

SIX EDGERLY PLACE  
BOSTON, MA  
02116

WWW.TAPPE.COM  
TEL 617.451.0200  
FAX 617.451.3899



**GARCIA•GALUSKA•DESOUSA**  
INC.  
CONSULTING ENGINEERS  
370 FAUNCE CORNER ROAD, DARTMOUTH, MA  
508 • 558-5750 • FAX 508-998-5883 • E-MAIL info@ggd-inc.com  
02747-7-1217

Phase Two Renovations  
SOUTH SHORE  
CHARTER SCHOOL  
Norwell, Massachusetts

Norwell, Massachusetts

[illegible]


Project: A0311.10  
Date: 03/24/04  
Scale: 3/32" = 1' 0"  
Drawn By: M.L.P.  
Checked By: J.M.C.  
Copyright 2004, Teepe Associates, Inc.

**MAIN LEVEL PLAN**

**LOW TENSION**

## E1.03

ISSUED FOR BID

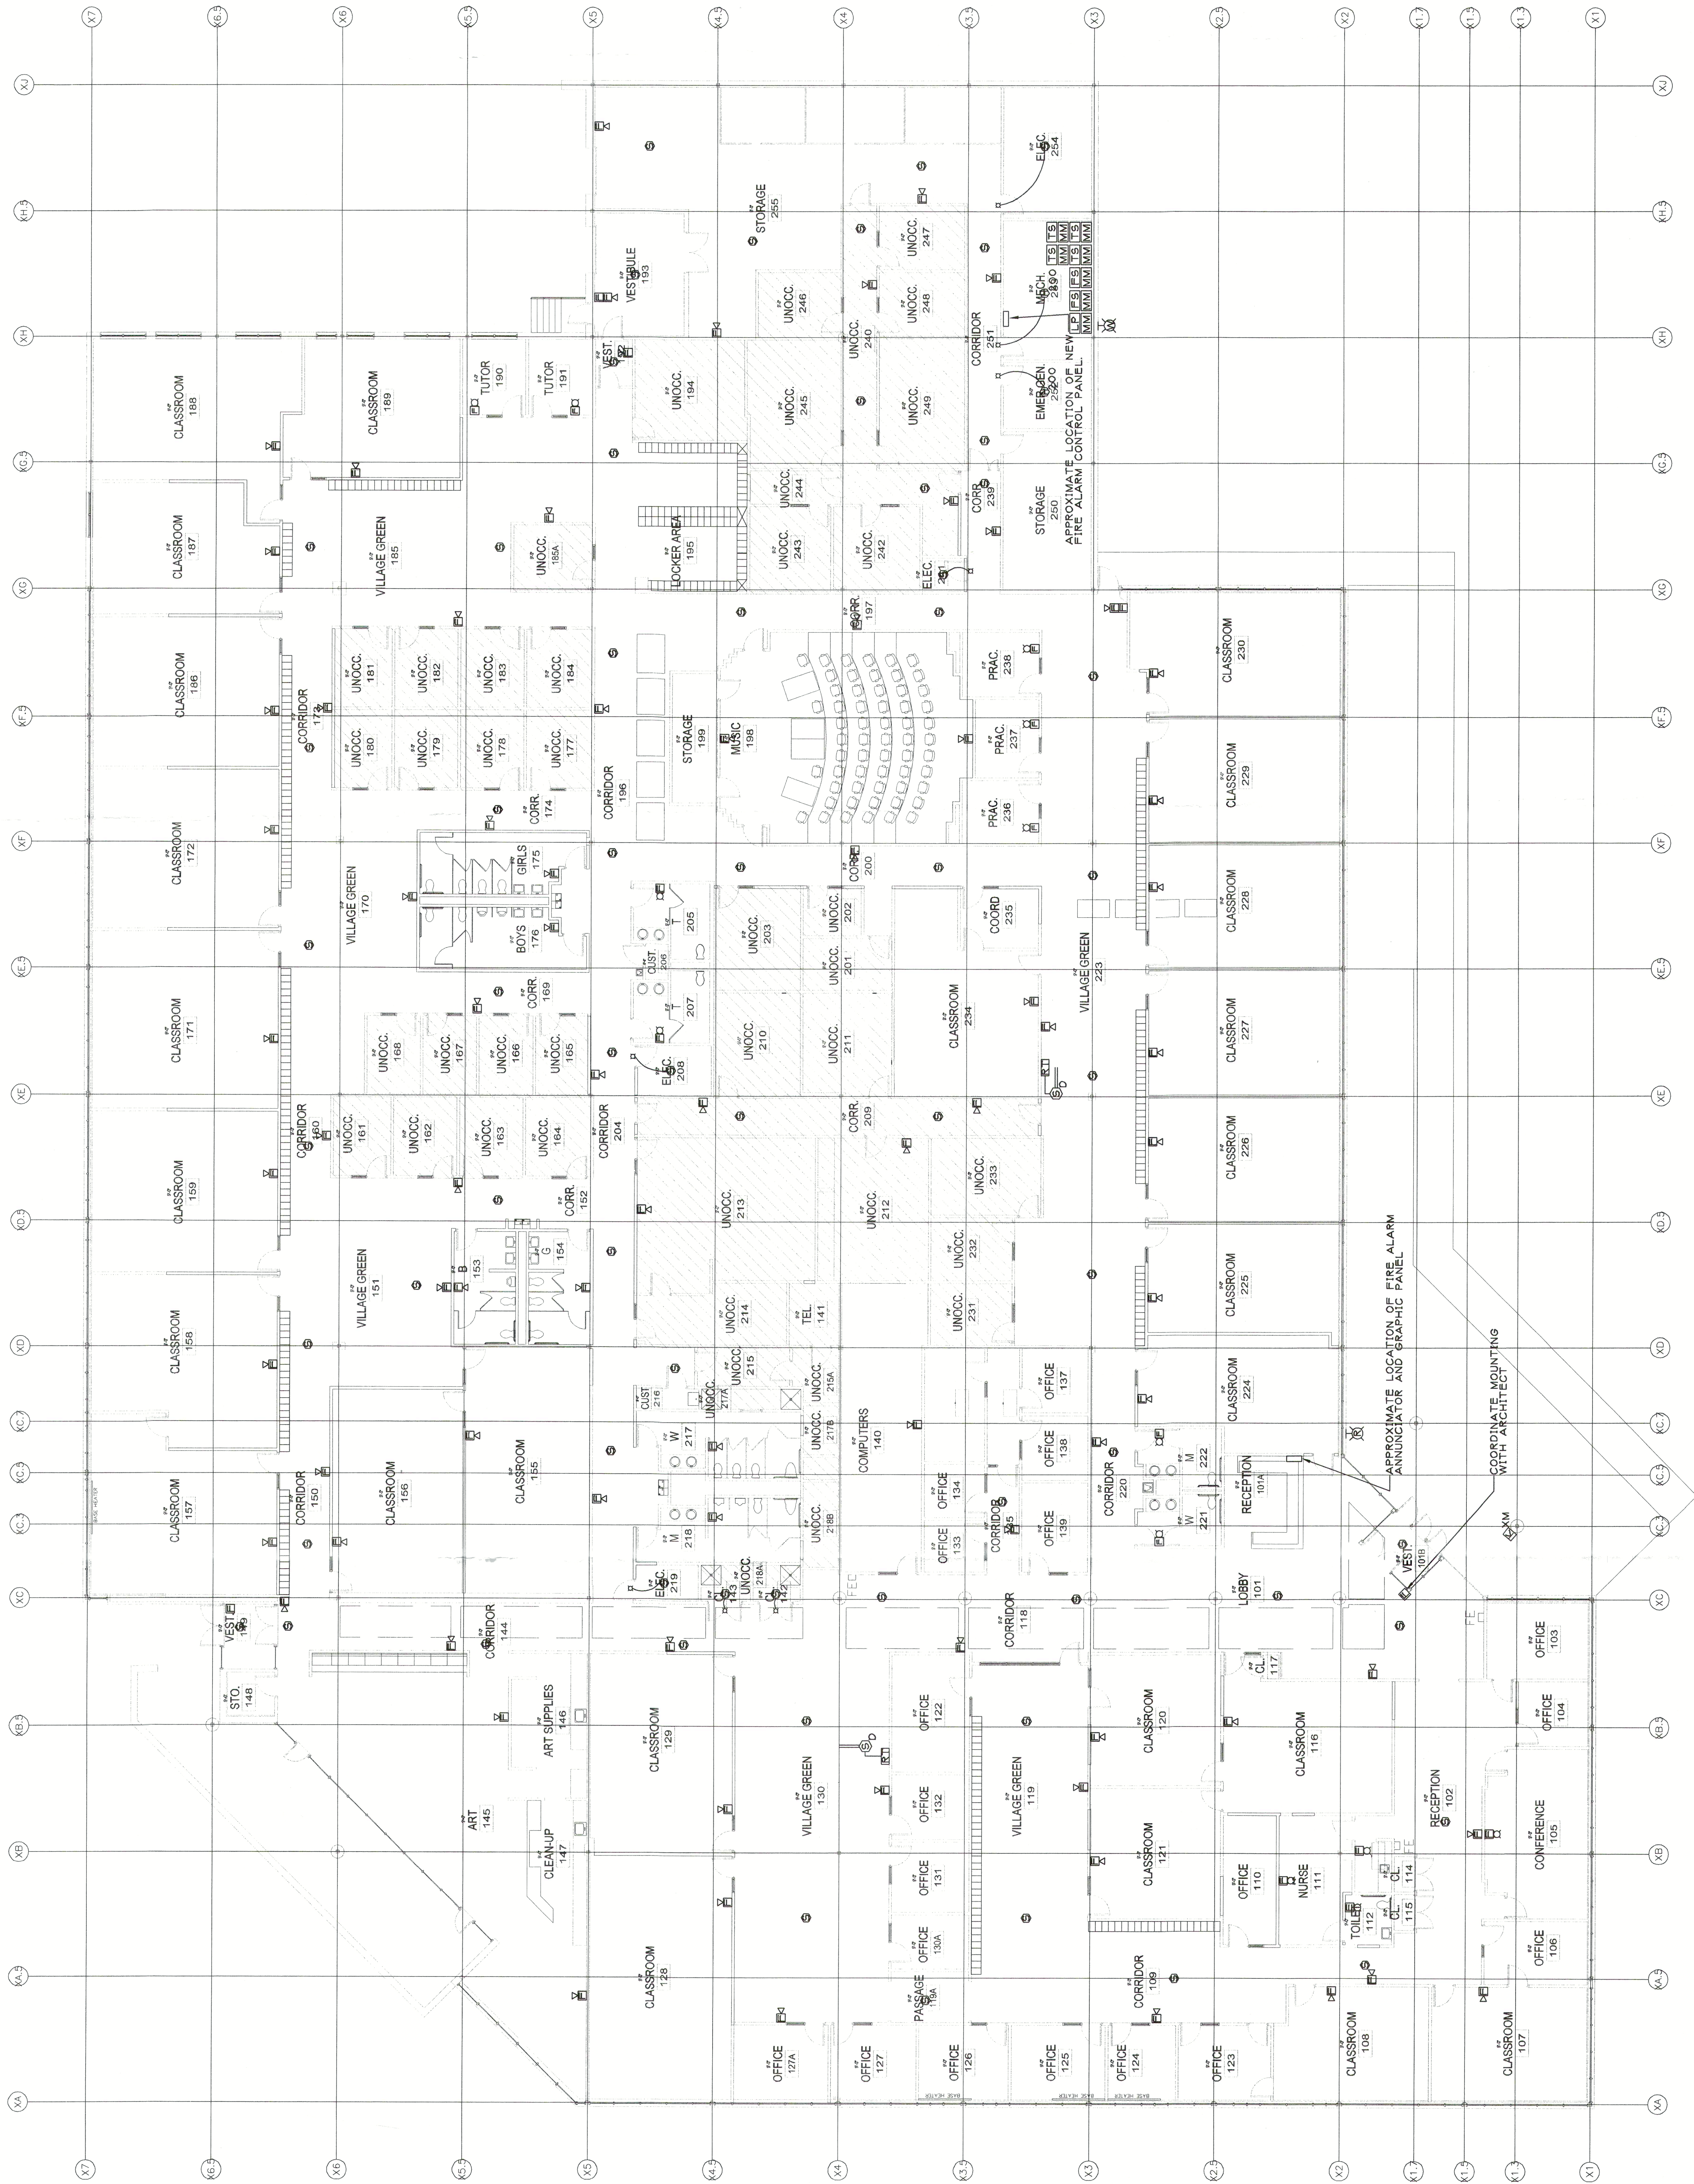

- BRANCH CIRCUIT NOTES:
1. COORDINATE EXACT LOCATION OF ALL DEVICES AND EQUIPMENT W/ARCHITECT PRIOR TO INSTALLATION.
2. REFER TO MECHANICAL PLANS FOR ANY CHANGES AND FOR EXACT LOCATION OF ALL DEVICES AND EQUIPMENT.
3. WIRING IS SHOWN ON DRAWINGS ONLY FOR SPECIFIC ROUTES OR SPECIAL CONDITIONS.
4. WIRING AND CONDUIT SHALL BE REQUIRED TO BE IDENTIFIED BY CIRCULAR CIRCUIT NUMBERS AND PANEL DESIGNATIONS.
5. ALTHOUGH ALL BRANCH CIRCUIT WIRING AND CONDUIT IS NOT SHOWN, IT IS THE INTENT OF THESE DOCUMENTS THAT A COMPLETE BRANCH CIRCUIT WIRING SYSTEM BE INSTALLED.
6. ALL BRANCH CIRCUIT CONDUCTORS SHALL BE TYPE MC 90X CONDUCTIVITY, COPPER WITH MINIMUM 600 VOLTS RATED UNLESS OTHERWISE NOTED.
7. REFER TO FIELD PROTECTION PLANS FOR ANY CHANGES AND FOR EXACT LOCATION OF ALL DEVICES, FUSE, CIRCUIT BREAKER, AND ON/OFF SWITCH, TAMPER SWITCH, ETC.

1 MAIN LEVEL PLAN - LOW TENSION  
E103 SCALE: 3/32"=1'-0"