

RA LONG HIGH SCHOOL KITCHEN REMODEL

PROJECT TEAM

OWNER

LONGVIEW SCHOOL DISTRICT
2080 38TH AVENUE
LONGVIEW, WA 98632
PHONE: (360) 575-7854
CONTACT: BILL OFTSUN
E-MAIL: boftsun@longview.k12.wa.us

ARCHITECT

COLLINS ARCHITECTURAL GROUP PS
950 12th AVE SUITE 200
LONGVIEW WA 98632
PHONE: (360) 425-0000
CONTACT: JARED BRADSHAW
E-MAIL: jared@johanssonwing.com

ELECTRICAL

ATHAY AND ASSOCIATES
411 N.E. 83rd STREET
VANCOUVER, WA 98665
PHONE: (360) 574-0199
CONTACT: RON ATHAY
E-MAIL: rathay@athayeng.com

INDEX OF DRAWINGS


ARCHITECTURAL

A3.0 FLOOR PLANS

ELECTRICAL

E0.1 ELEC SYMBOLS & SCHEDULES
E2.0 FIRST FLOOR PWR/LIGHTING

VICINITY MAP

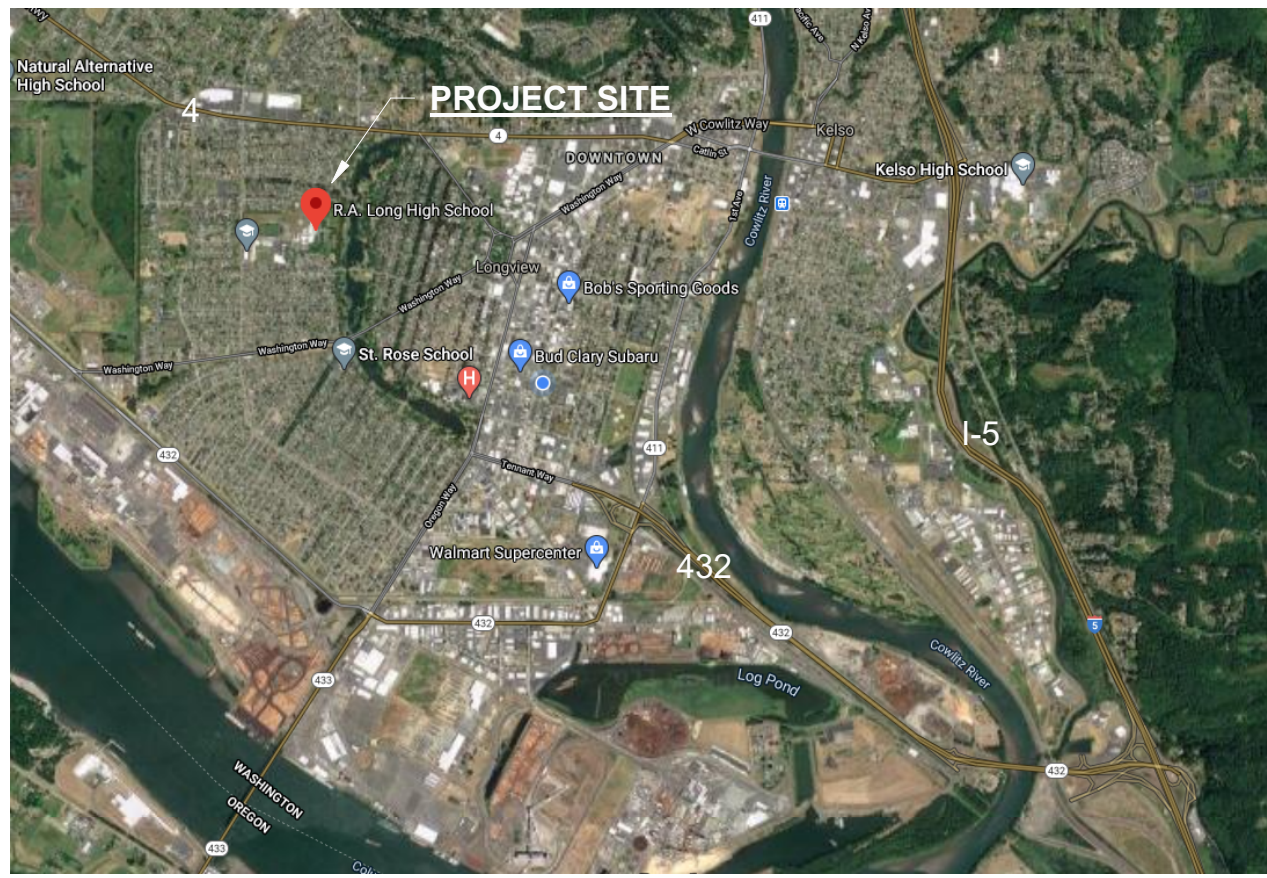


PROJECT DESCRIPTION

THIS PROJECT SCOPE INCLUDES THE ADDITION OF TWO NEW SINKS, LVT FLOORING, CEILING TILES, WALL FINISHES, AND AN ICEMAKER. IN ADDITION THE MICROWAVES IN THE ADJACENT ROOM ARE BEING REWIRED TO BE ON SEPARATE CIRCUITS.

GENERAL NOTES


- ALL PLUMBING WORK SHALL BE DESIGN BUILD.
- CLEAN EXISTING CEILING TILE GRID AND ALL HVAC / FIRE ALARM EQUIPMENT

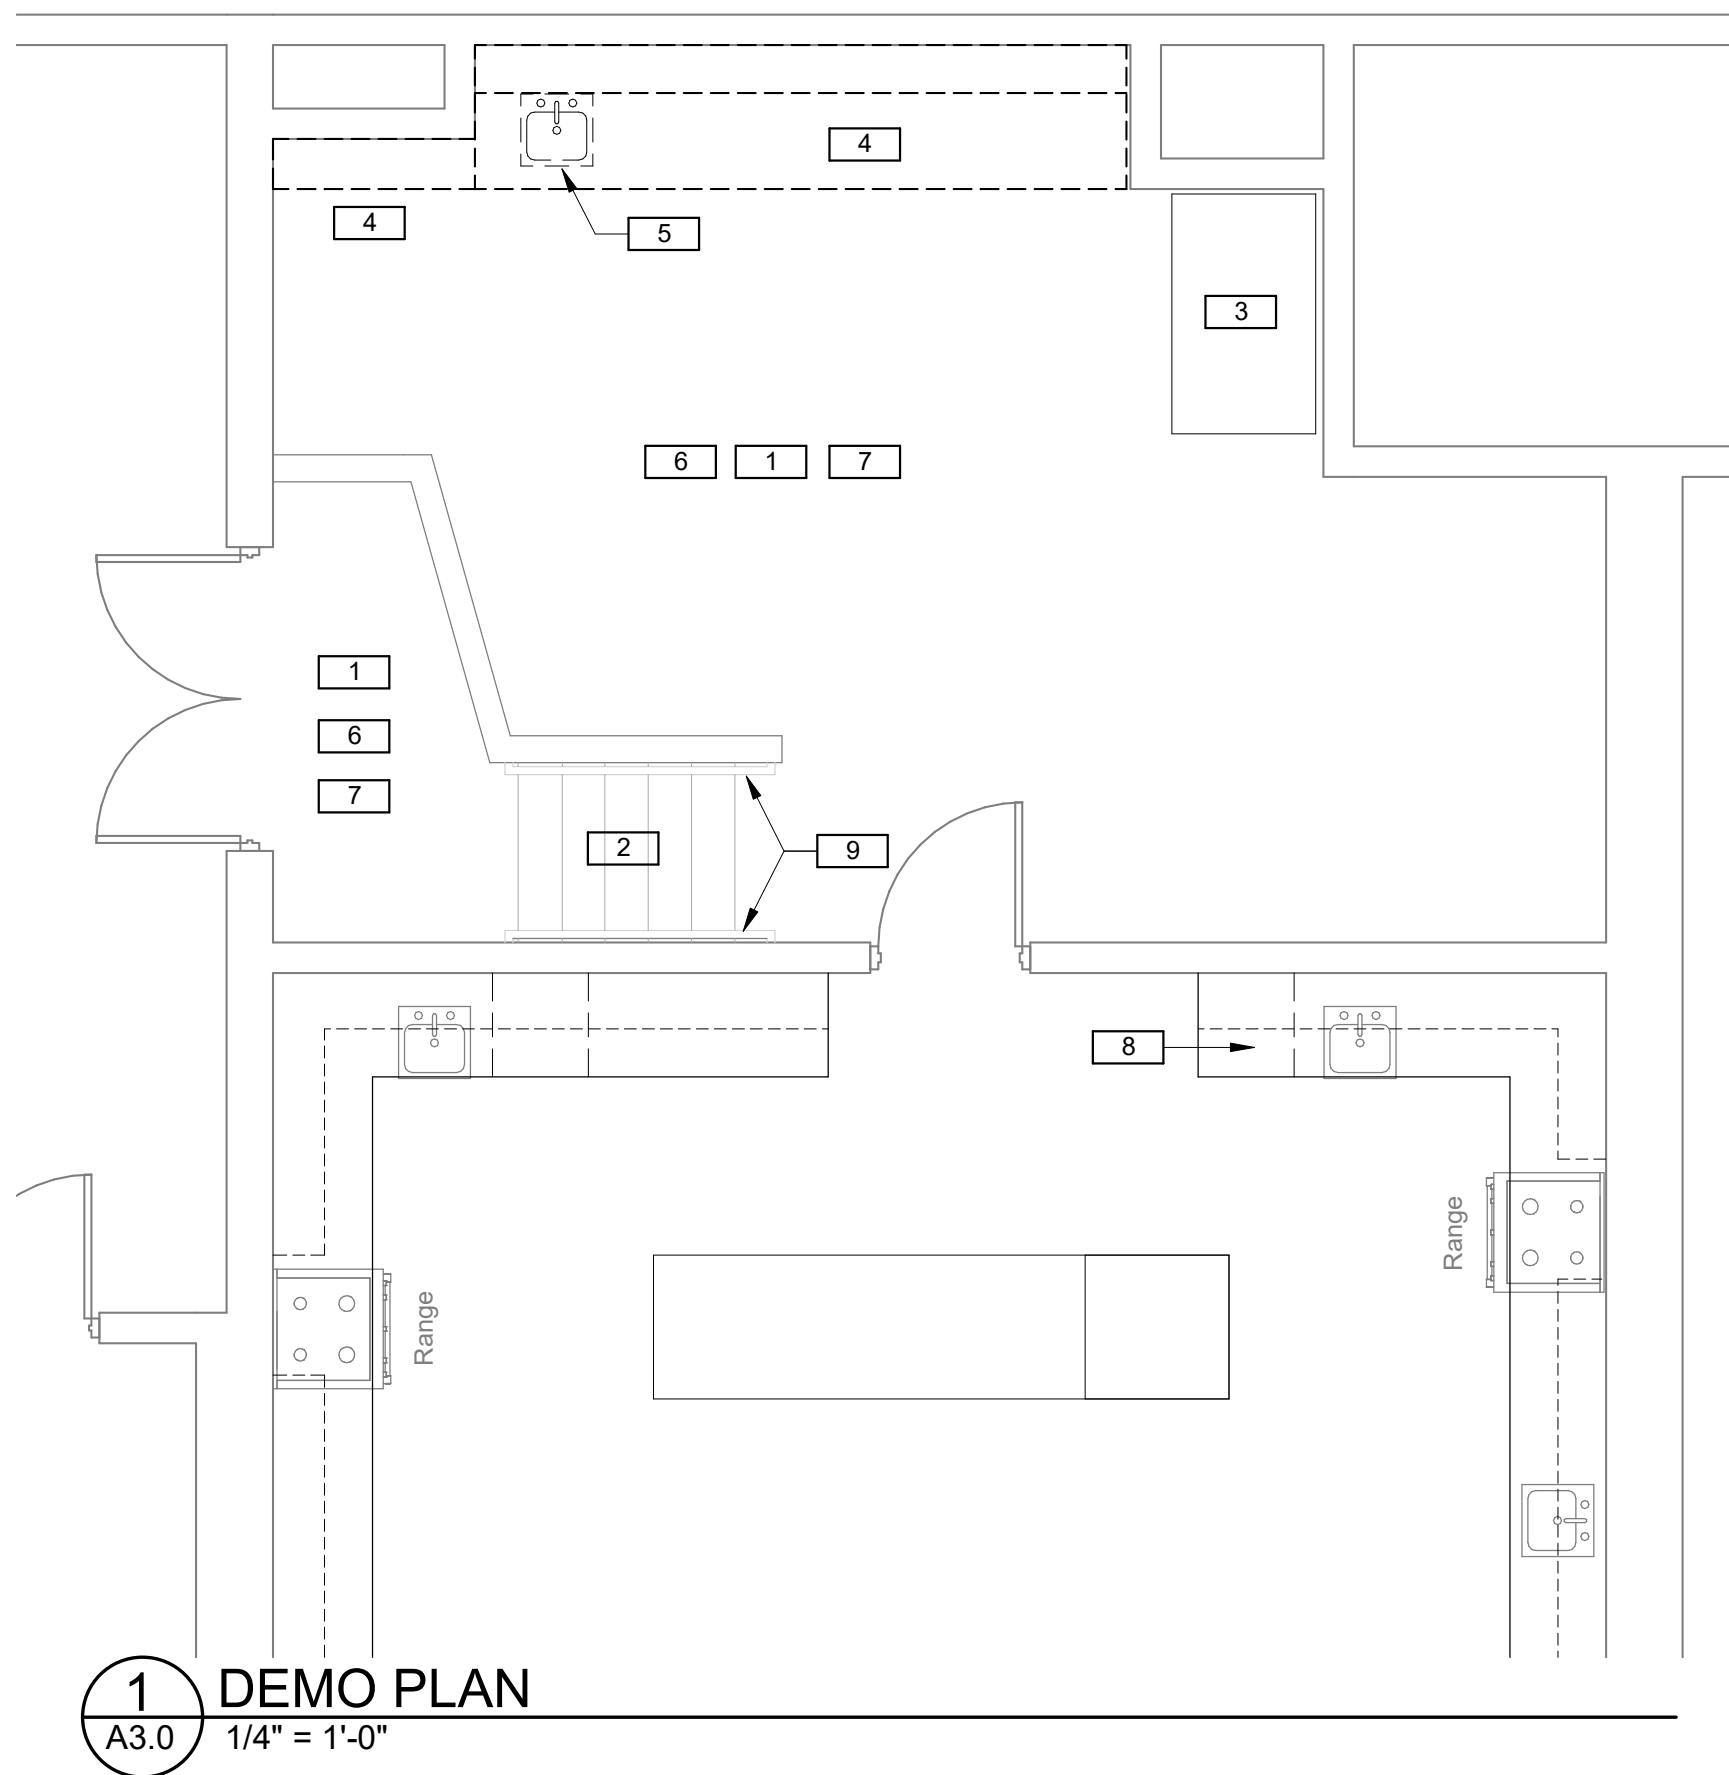

1 DEMO PLAN
A3.0 1/4" = 1'-0"

DEMO PLAN KEYNOTES:

- | | |
|---|--|
| 1 REMOVE EXIST VCT FLOORING THROUGHOUT ENTIRE ROOM. PREP EXISTING CONCRETE FLOOR FOR NEW LVT FLOORING ACCORDING TO LVT MANUFACTURER RECOMMENDATIONS | 6 REMOVE EXISTING RUBBER BASE THROUGHOUT ENTIRE ROOM |
| 2 REMOVE EXIST STAIR TREADS. PREP FOR NEW RUBBER TREADS ACCORDING TO RUBBER STAIR TREAD MANUFACTURER RECOMMENDATIONS | 7 PREP WALLS THROUGHOUT ENTIRE ROOM FOR NEW PAINT INCLUDING THE STAIR HALF WALL. PATCH WALLS WHERE CASEWORK HAS BEEN REMOVED |
| 3 EXISTING STAND ALONE FREEZER TO BE RELOCATED | 8 REMOVE EXISTING DISHWASHER. SALVAGE AND RETURN TO OWNER |
| 4 REMOVE EXISTING CABINETRY AND SHELVING. | 9 PREP EXISTING HANDRAILS FOR NEW PAINT |
| 5 REMOVE EXISTING SINK. SALVAGE PLUMBING FOR REUSE | |

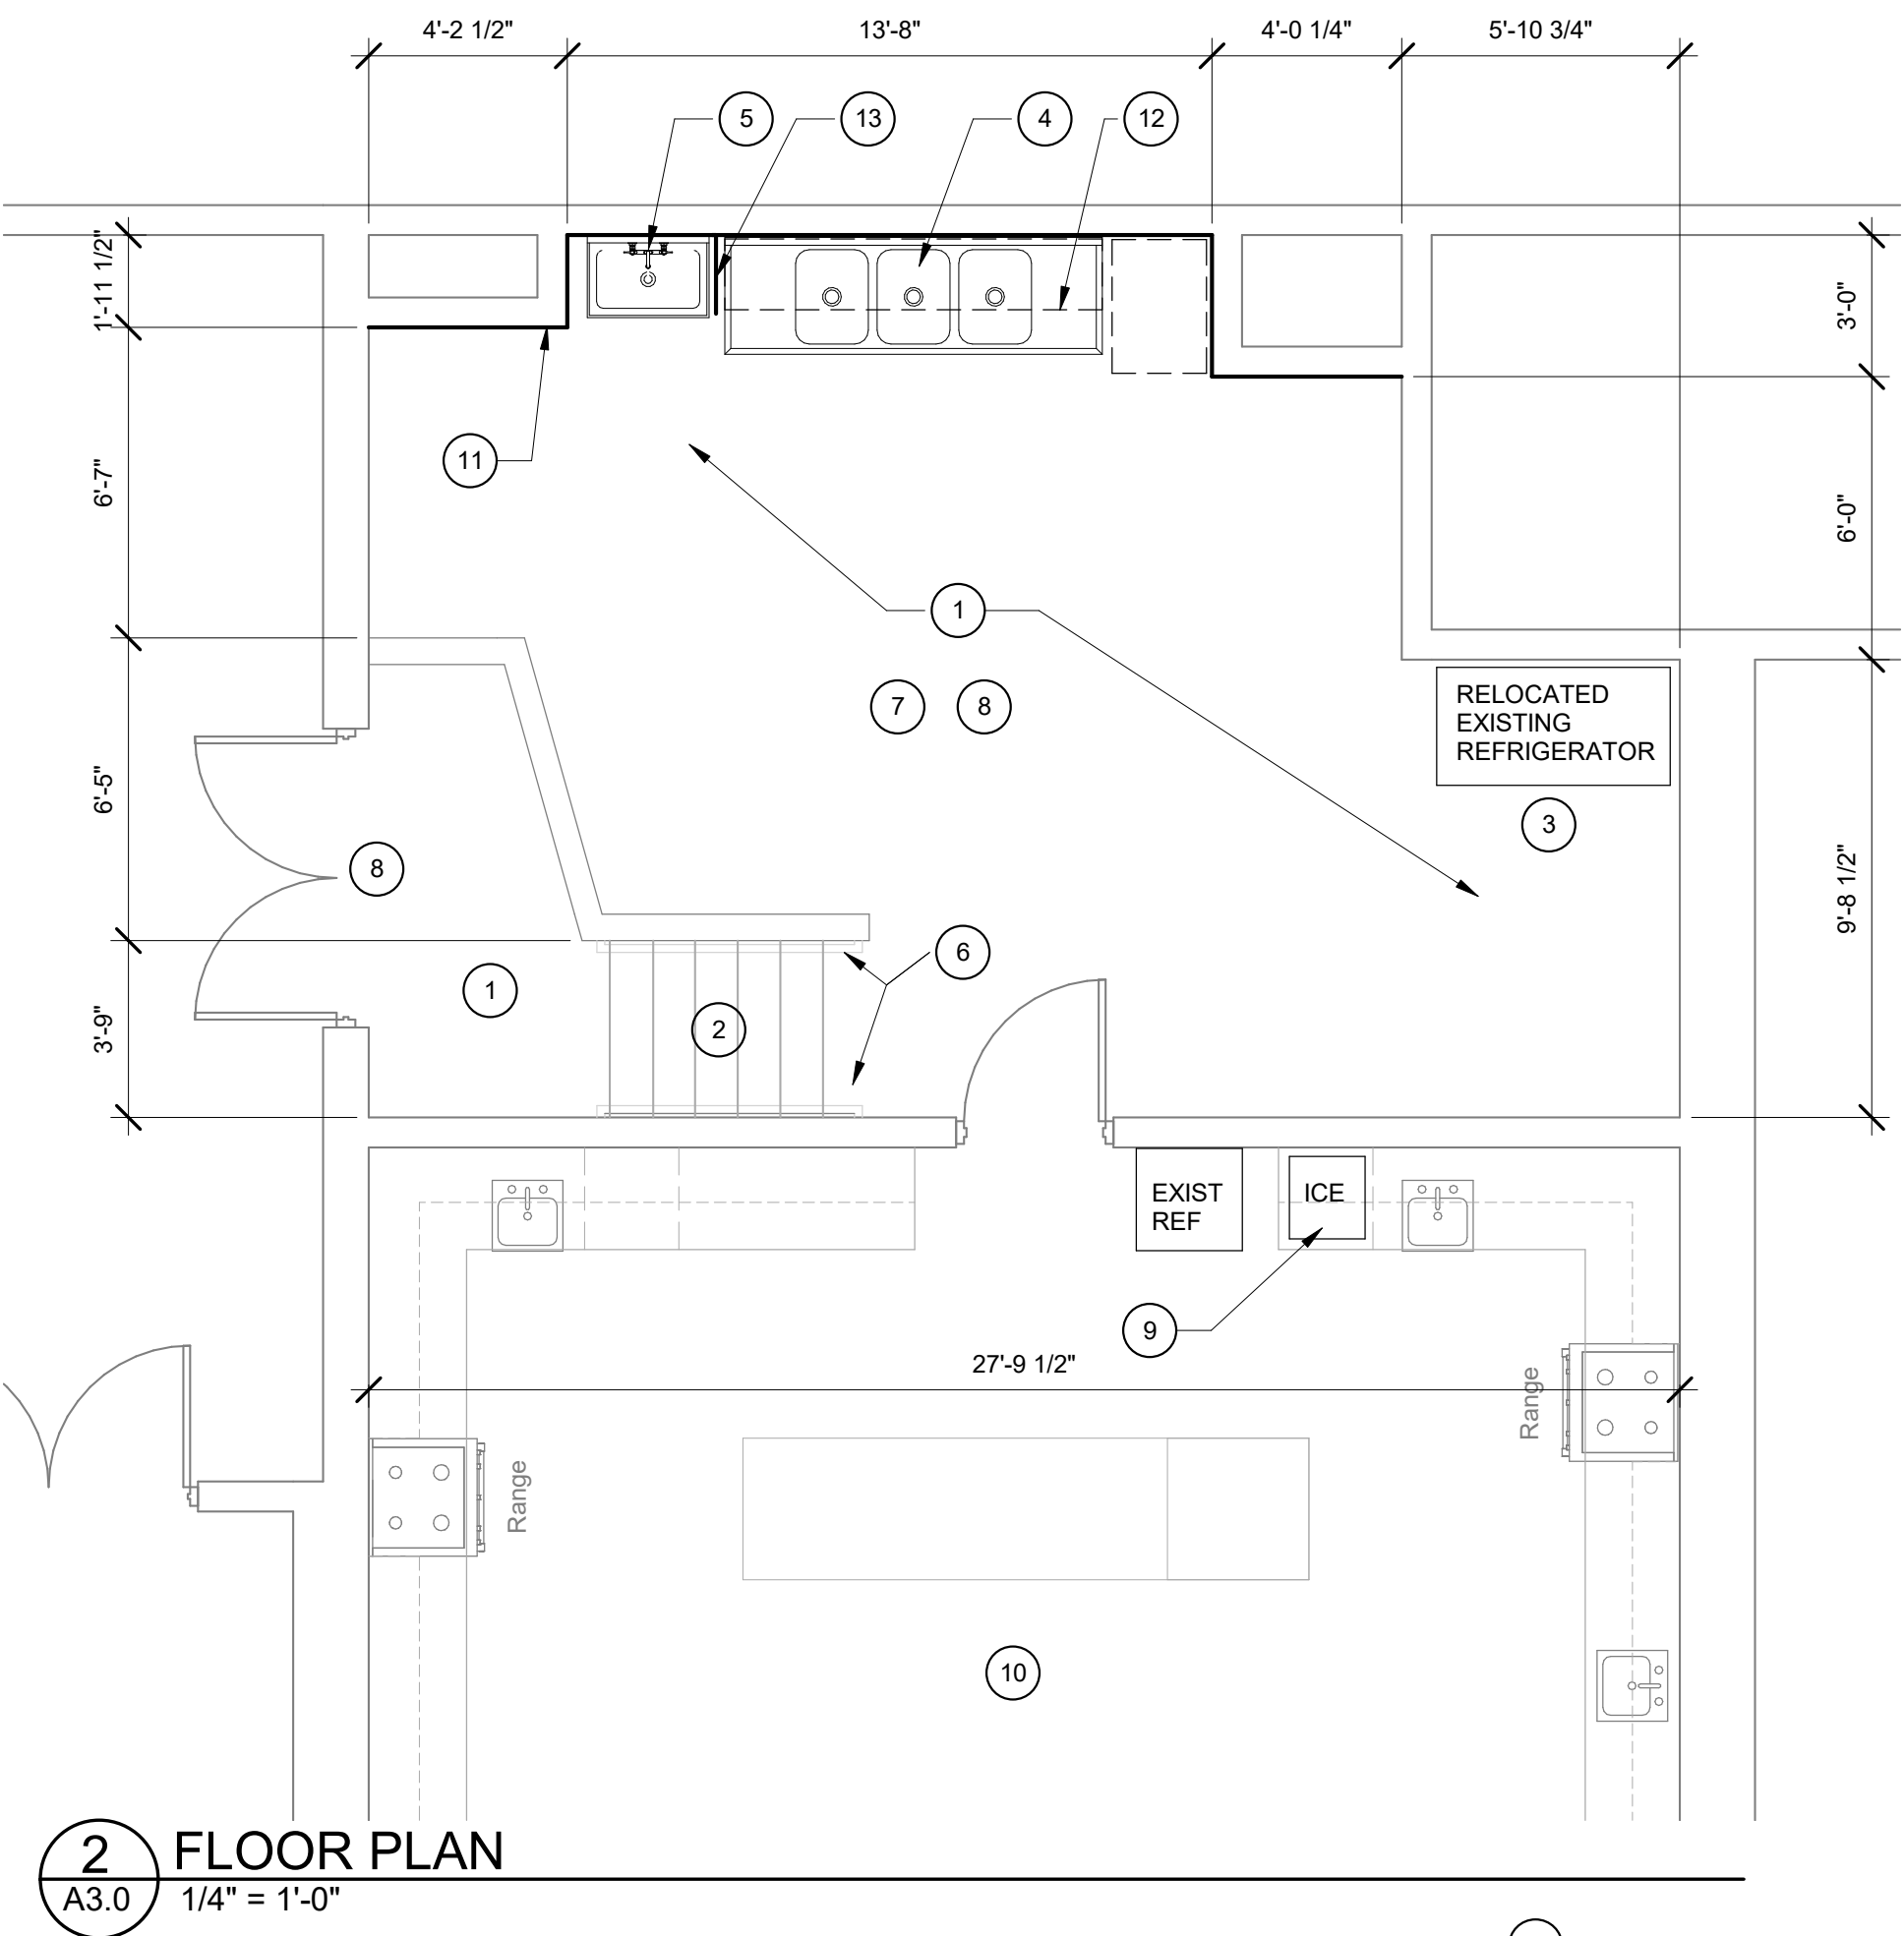


2 FLOOR PLAN
A3.0 1/4" = 1'-0"

FLOOR PLAN KEYNOTES:

- LVT FLOORING AND RUBBER BASE THROUGHOUT ROOM. BASIS OF DESIGN : ARMSTRONG FLOORING NA194 AVILA OAK MADRID GREY LVT WITH ANY REQUIRED TRANSITION STRIPS
BASIS OF DESIGN : FLEXCO BLACK RUBBER BASE.
- RUBBER STAIR TREADS. BASIS OF DESIGN: TREAD ULINE: 3653 - INDOOR VINYL - BLACK. BASIS OF DESIGN: RISER ULINE: H-5196 VINYL - BLACK.
- RELOCATE EXISTING FREEZER TO THIS LOCATION
- STAINLESS STEEL TRIPLE COMPARTMENT SINK. USE EXIST ADJACENT PLUMBING
BASIS OF DESIGN: REGENCY 91" 18-GAUGE STAINLESS STEEL THREE COMPARTMENT #600S317172G
BASIS OF DESIGN: (FAUCET) WATERLOO 1.15 GPM WALL-MOUNTED PRE-RINSE FAUCET #750PRW814
- STAINLESS STEEL SINGLE HANDWASH SINK
BASIS OF DESIGN: SANI-LAV 5A1F-0.5 ADA COMPLIANT WALL MOUNT SINK WITH FAUCET, LOW-FLOW 0.5 GPM
- PAINT EXIST STEEL HANDRAILS


- PAINT ALL WALLS THROUGHOUT ENTIRE ROOM WITH SEMI-GLOSS PAINT
- INSTALL PANIC HARDWARE WITH INTERGRAL BATTERY POWERED CARD SWIPE DOOR ACCESS PROVIDED BY OWNER ON EXISTING DOOR.
- PROVIDE AND INSTALL UNDER COUNTER ICE MAKER IN PLACE OF EXISTING DISHWASHER. REUSE EXISTING PLUMBING PROVIDING THE REQUIRED DRAIN AIR GAP. PROVIDE A DRAIN PUMP FOR ICE MAKER IN ORDER TO DRAIN INTO ADJACENT SINK PLUMBING.
BASIS OF DESIGN: Ice-O-Matic UCG100A
- REVISE EXISTING MICROWAVE WIRING TO PROVIDE SEPARATE CIRCUITS FOR EACH MICROWAVE. SEE ELECTRICAL
- FRP FULL HEIGHT, BASIS OF DESIGN: CRANE COMPOSITES VARIETEX - LINEN TEXTURE
- 18"x96" METAL WIRE WALL DRYING SHELVING ABOVE TRIPLE SINK
- STAINLESS STEEL WALL MOUNT SPLASH GUARD (20" W X 20" H)

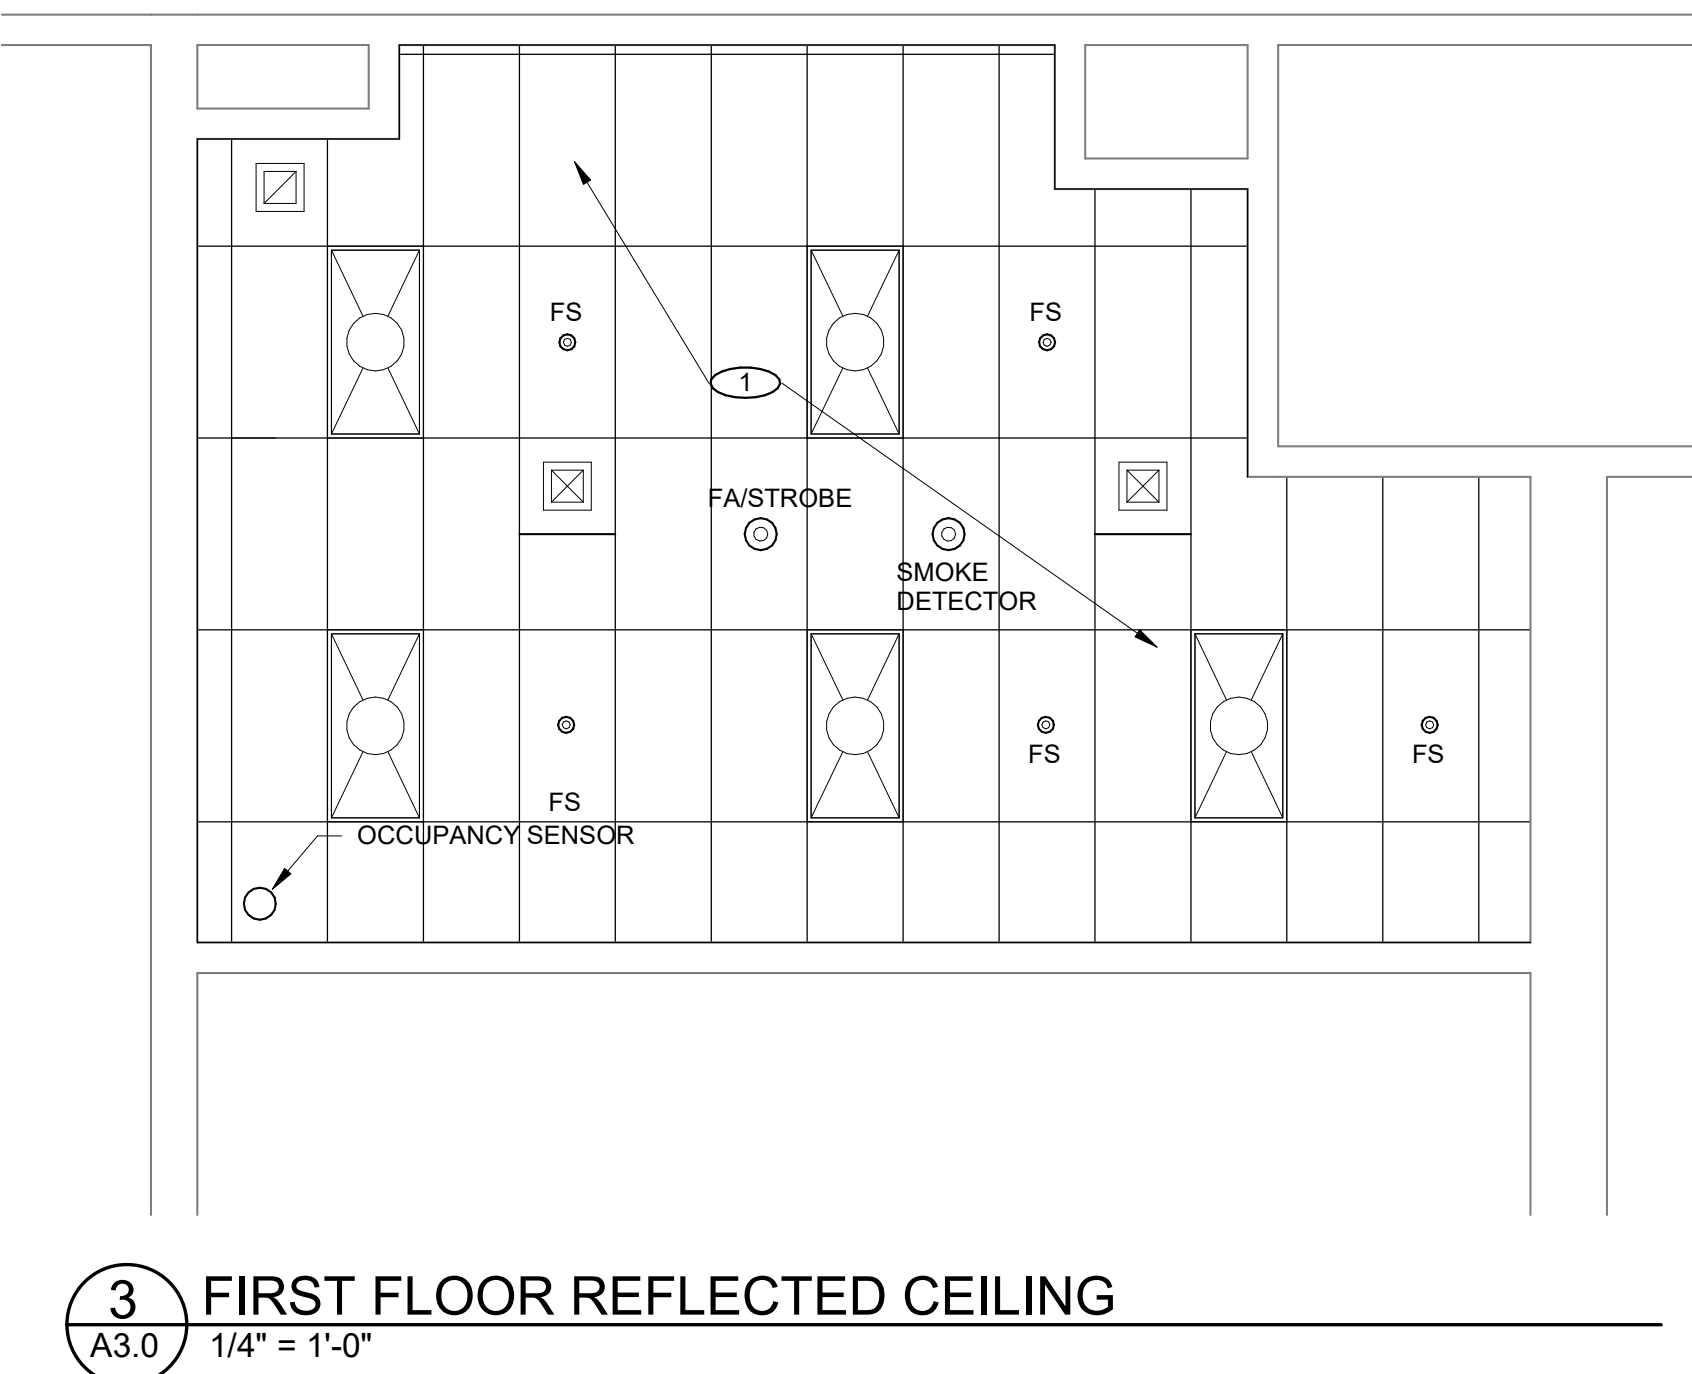

3 FIRST FLOOR REFLECTED CEILING
A3.0 1/4" = 1'-0"


REFLECTED CEILING PLAN KEYNOTES:

- REPLACE ALL CEILING TILES WITH NEW. GRID TO REMAIN. DISPOSE OF EXISTING TILES.
BASIS OF DESIGN: ARMSTRONG: 2X4 CERAMAGUARD - FINE FISSURED

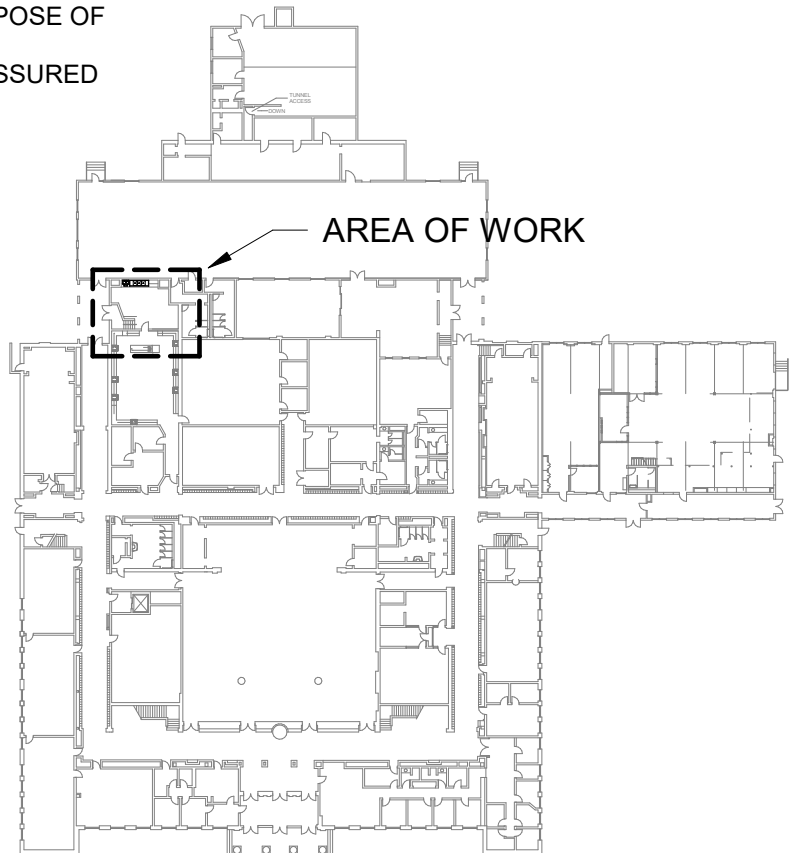

KEYPLAN

Revision Schedule		
#	Date	Description

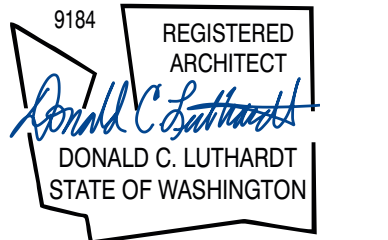

LPS - RA LONG
KITCHEN REMODEL
2903 NICHOLS BLVD, LONGVIEW, WA 98632

PERMIT SET
6-23-2023

FLOOR
PLANS

23038

SHEET NO.

A3.0

1. SCOPE: PROVIDE ALL LABOR, MATERIAL, AND WORK NECESSARY TO PROVIDE A COMPLETE AND OPERABLE ELECTRICAL INSTALLATION.
2. SECURE AND PAY FOR ALL REQUIRED PERMITS, AND INSPECTIONS.
3. PROVIDE A COMPLETE SET OF ELECTRONIC SUBMITTAL CATALOG CUTS FOR ALL EQUIPMENT BEING SUPPLIED TO THIS PROJECT.
4. REVIEW ALL CONTRACT DOCUMENTS AND PROVIDE ALL ELECTRICAL MATERIAL AND WORK INDICATED THEREON.
5. RETURN APPROVED ELECTRICAL PERMIT PLANS TO THE OWNER AT THE END OF THE PROJECT.
6. APPROVAL OF SHOP DRAWINGS OR ALTERNATE EQUIPMENT SUBMITTALS DOES NOT REMOVE THE CONTRACTOR'S REQUIREMENT TO COMPLY WITH THE CONTRACT DOCUMENT'S INTENT.
7. WARRANTY: ALL WORK AND MATERIAL SHALL BE WARRANTED FOR ONE YEAR FROM SUBSTANTIAL COMPLETION.
8. PROVIDE ALL MATERIAL AND LABOR IN COMPLIANCE WITH THE NEC, AND ALL OTHER APPLICABLE NATIONAL, STATE AND LOCAL CODES.
9. ALL WORK SHALL BE DONE TO THE BEST INDUSTRY PRACTICES AND STANDARDS.
10. REPAIR ANY DAMAGE TO EXISTING ELECTRICAL EQUIPMENT CAUSED BY PROJECT WORK. PATCH ALL SURFACE OPENED OR DAMAGE BY THIS PROJECT TO MATCH ADJACENT SURFACE. VERIFY REQUIREMENTS WITH ARCHITECT.
11. ALL MATERIAL SUPPLIED SHALL BE U.L. LISTED FOR THE INTENDED PURPOSE.
12. ALL FEEDERS AND BRANCH CIRCUITRY SHALL BE IN EMT RACEWAY, OR MCCABLE. CONDUCTORS SHALL BE COPPER, THWN/THHN.
ALL CIRCUITRY SHALL BE CONCEALED IN OCCUPIED SPACES UNLESS INDICATED SURFACE OR EXPOSED ON DRAWINGS.
13. OUTLET BOXES, PRESSED STEEL, 4" X 4" X 1 1/2"D MINIMUM.
14. RECEPTACLES AND LIGHT SWITCHES SHALL BE COMMERCIAL GRADE, 120V, 20 AMP. APPROVED MANUFACTURERS: HUBBELL, P& S, AH, LEVITON.
15. OCCUPANCY SENSORS: CEILINGS: DUAL TECHNOLOGY, 360 DEGREE; WALL SWITCH: INCLUDE A POSITIVE OFF SWITCH. APPROVED MANUFACTURERS: WATT STOPPER, SENSOR SWITCH, LEVITON, OR AS APPROVED.
16. OUTLET AND SWITCH COVER PLATES: STAINLESS STEEL.
17. SAFETY SWITCHES: HEAVY DUTY, FUSED, WITH INTERLOCKING DOORS AND FUSE REJECTION CLIP HOLDERS. SQ. D. , GE, SIEMENS, CUTLER-HAMMER/WESTINGHOUSE.
18. FUSES: U.L. CLASS RK5, T.D.
19. GROUNDING: PROVIDE GROUND CONDUCTOR IN ALL NEW CIRCUITRY. PROVIDE ALL CODE REQUIRED GROUNDING.

[illegible]

PANEL SCHEDULE		G LOCATION:		HOME ECONOMICS	
225A BUSS 120/208v 3ph 4w		MAIN (LUGS)		100 AMP FEEDER (E)	
NO	DESCRIPTION	KVA	BKR	BKR	KVA
1	L LTC - RM 115 (E)	1.20	20A*	20A*	0.90 DCO - RM 115, 115B (E)
3	CB OFF				0.90 DCO - RM 115, 115B (E)
5	L LTC - RM 22,23,114A (E)	1.20	20A*	20A*	0.72 DCO - HALLWAY, RM 22,23,114A (E)
7	L LTC - RM 114 (E)	1.20	20A*	20A*	0.72 DCO - RM 4,20,22,114 (E)
9	L LTC - RM 114 (E)	1.20	20A*	20A*	0.18 DCO - RM 114(E)
11	L LTC - RM 114 (E)	1.20	20A*	20A*	0.18 DCO - RM 114 (E)
12	SPARE CB (E) CB OFF		20A*	20A*	0.18 DCO - RM 114 (E)
13	SPARE CB (E) CB OFF		20A*	20A*	1.00 HOOD LTS RM 114 MICROWAVE (E)
17	K DISHWASHER (E) CB OFF	0.36	20A*	20A*	0.18 DCO - RM 114 (E)
19	K ICE MACHINE (N)	1.00	20A*	20A*	0.90 DCO - RM 114 (E), MICROWAVE (E)
21	SPARE CB (E) CB OFF		20A*	20A*	0.18 DCO - RM 114 (E)
23	K COOK TOP(E)	3.00	30A*	30A*	0.18 DCO - RM 114 (E)
25			2P	2A*	0.18 DCO - RM 114 (E)
27	SPARE CB		20A*	20A*	1.00 RM 114 (E), HOOD/MICROWAVE
29	K MICROWAVE/HOOD RECIRCUTED	0.90	20A*	20A*	0.90 DISPOSAL (E)
31	K MICROWAVE/HOOD RECIRCUTED	0.90	30A*	30A*	0.00 DISHWASHER (CB OFF) (E)
33	K DCO 5 REFRIG. RECIRCUTED	0.70	B	20A*	0.18 DCO - RM 114 (E)
35	L WASHER RM 114A (E)	1.00	20A*	20A*	0.18 DCO - RM 114 (E)
37	D DCO RM 114 (E)	0.18	20A*	20A*	0.90 RM 114 (E), MICROWAVE (E)
39	D DCO RM 114 (E)	0.18	20A*	20A*	0.18 DCO - RM 114 (E)
41	D DCO RM 114 - REFRIG (E)	0.78	20A*	20A*	0.90 HOOD LTS RM 114 - MICROWAVE (E)
LOAD CALCULATION					
LIGHTING		6.18	7.73		
LTC @ 125%					
MOTORS		0.90	0.23		
LROST @ 25%					
OUTLETS		6.00	0.00		
DEDUCTED OUTLETS			6.00		
DEMAND OUTLETS95%K					
KITCHEN		11.20			
DEMAND KITCHEN			7.28		
HEAT		0.00	0.00		
MISCELLANEOUS		1.36	1.36		
WELDERS					
CONNECTED KVA		25.64			
DEMAND KVA			23.49		
				71.22 AMP	EXISTING PANEL "G"
				65.25 AMP	REVISED SCHEDULE

CIRCUIT BREAKER CODES

S = SHUNT TRIP BREAKERS
 * = EXISTING C.B. - ALL OTHERS NEW - (N) NEW LOAD
 SPARE = CIRCUIT BREAKER
 BLANK = C.B. POSITION
 K = KITCHEN
 L = LIGHTING
 M = MOTORS
 D = OUTLETS
 H = HEAT
 X = MISCELLANEOUS
 W = WELDERS

TC = 0 DEDICATED OUTLETS
 K = 12 DEMAND KITCHEN

SOME SYMBOLS MAY NOT APPEAR ON DRAWINGS INDICATE SYMBOLS INDICATE EQUIPMENT	
	BRANCH CIRCUIT IN WALL OR CEILING
	BRANCH CIRCUIT EXPOSED
	BRANCH CIRCUIT IN FLOOR OR EARTH
	BRANCH CIRCUIT EXISTING
	TELEPHONE LINE
	TELL DARKER LINES INDICATE NEW
	TELL LIGHTER LINES INDICATE EXISTING
	HASH MARKS = # DP WIRES (NO HASH MARKS = 2 WIRES + 1 GROUND)
	HASH MARKS = # DP WIRES W/ HARD WIRE GROUND
	LIGHTING FIXTURE-FLUORESCENT-RECESSED MOUNT
	LIGHTING FIXTURE-FLUORESCENT-SURFACE MOUNT
	LIGHTING FIXTURE-FLUORESCENT-W/ EMERGENCY BATTERY INVERTER
	LIGHTING FIXTURE-EXISTING SHOWN DOTTED (TYPICAL TO REMOVE)
	LIGHTING FIXTURE-EXISTING SHOWN LIGHT LINED (TYPICAL TO REMOVE)
	LIGHTING FIXTURE-WALL MOUNT
	LIGHTING FIXTURE-RECESSED
	LIGHTING FIXTURE-CEILING MOUNT
	LIGHTING FIXTURE-WALL SCONCE
	LIGHTING FIXTURE-BRACKET MOUNT
	LIGHTING FIXTURE-EMERGENCY BATTERY PACK
	LIGHTING FIXTURE-EXIT LIGHT
	OCCUPANCY SENSOR, DUAL TECH
	OCCUPANCY SENSOR - DUAL TECH, 360°
	OCCUPANCY SENSOR RELAY
	DUPLEX CONVENIENCE OUTLET (DCO)
	SAFETY TYPE DCO
	DCO 120V W/ GROUND FAULT PROTECTION
	DCO 120V W/ SPLIT CONTROLS LABEL OCCUPANCY CONTROL
	QUADPLEX CONVENIENCE OUTLET
	DEDICATED DCO (HARD/ISO WIRE GROUND) 20 AMP
	DEDICATED DCO (SPECIFIC EQUIPMENT)
	DCO 208V W/ AS NOTED
	JUNCTION BOX
	FLOOR MOUNTED OUTLET - W/ AS NOTED
	CONNECTION TO EQUIPMENT
	MOTOR DRIVEN DEVICE
	= DEVICE OVER COUNTER
	LIGHTING SWITCH - SINGLE POLE
	LIGHTING SWITCH - SECTION AS NOTED
	LIGHTING SWITCH - THREE WAY
	LIGHTING SWITCH - FOUR WAY
	LIGHTING SWITCH - DIMMER
	LIGHTING SWITCH - KEYED
	LIGHTING SWITCH - PILOT LIGHTED
	MOTOR SWITCH - MOTOR RATED
	WALL SWITCH TYPE OCCUPANCY SENSOR

PANEL H: EXISTING LOAD: 43.35 KVA, NEW LOAD 44.71 KVA: INCREASE 1.4% OF CAPACITY
PANEL G: EXISTING LOAD: 26.41 KVA, NEW LOAD 23.49 KVA: DECREASE LOAD.

[illegible]

E0.1

06/16/2023


SHEET HEX NOTES:

- B

REVISE CIRCUITRY TO RECEPTACLE SERVING EXISTING REFRIGERATOR AS INDICATED. VERIFY REQUIREMENTS ON SITE.
- C

REVISE CIRCUITRY TO EXISTING MICROWAVE AS INDICATED. VERIFY REQUIREMENTS ON SITE.
- D

REVISE EXISTING DISH WASHER CONNECTION TO GFCI OUTLET TO SERVE NEW ICE MACHINE AS INDICATED. VERIFY REQUIREMENTS ON SITE. CONNECT TO EXISTING CIRCUITRY COMPLETE.

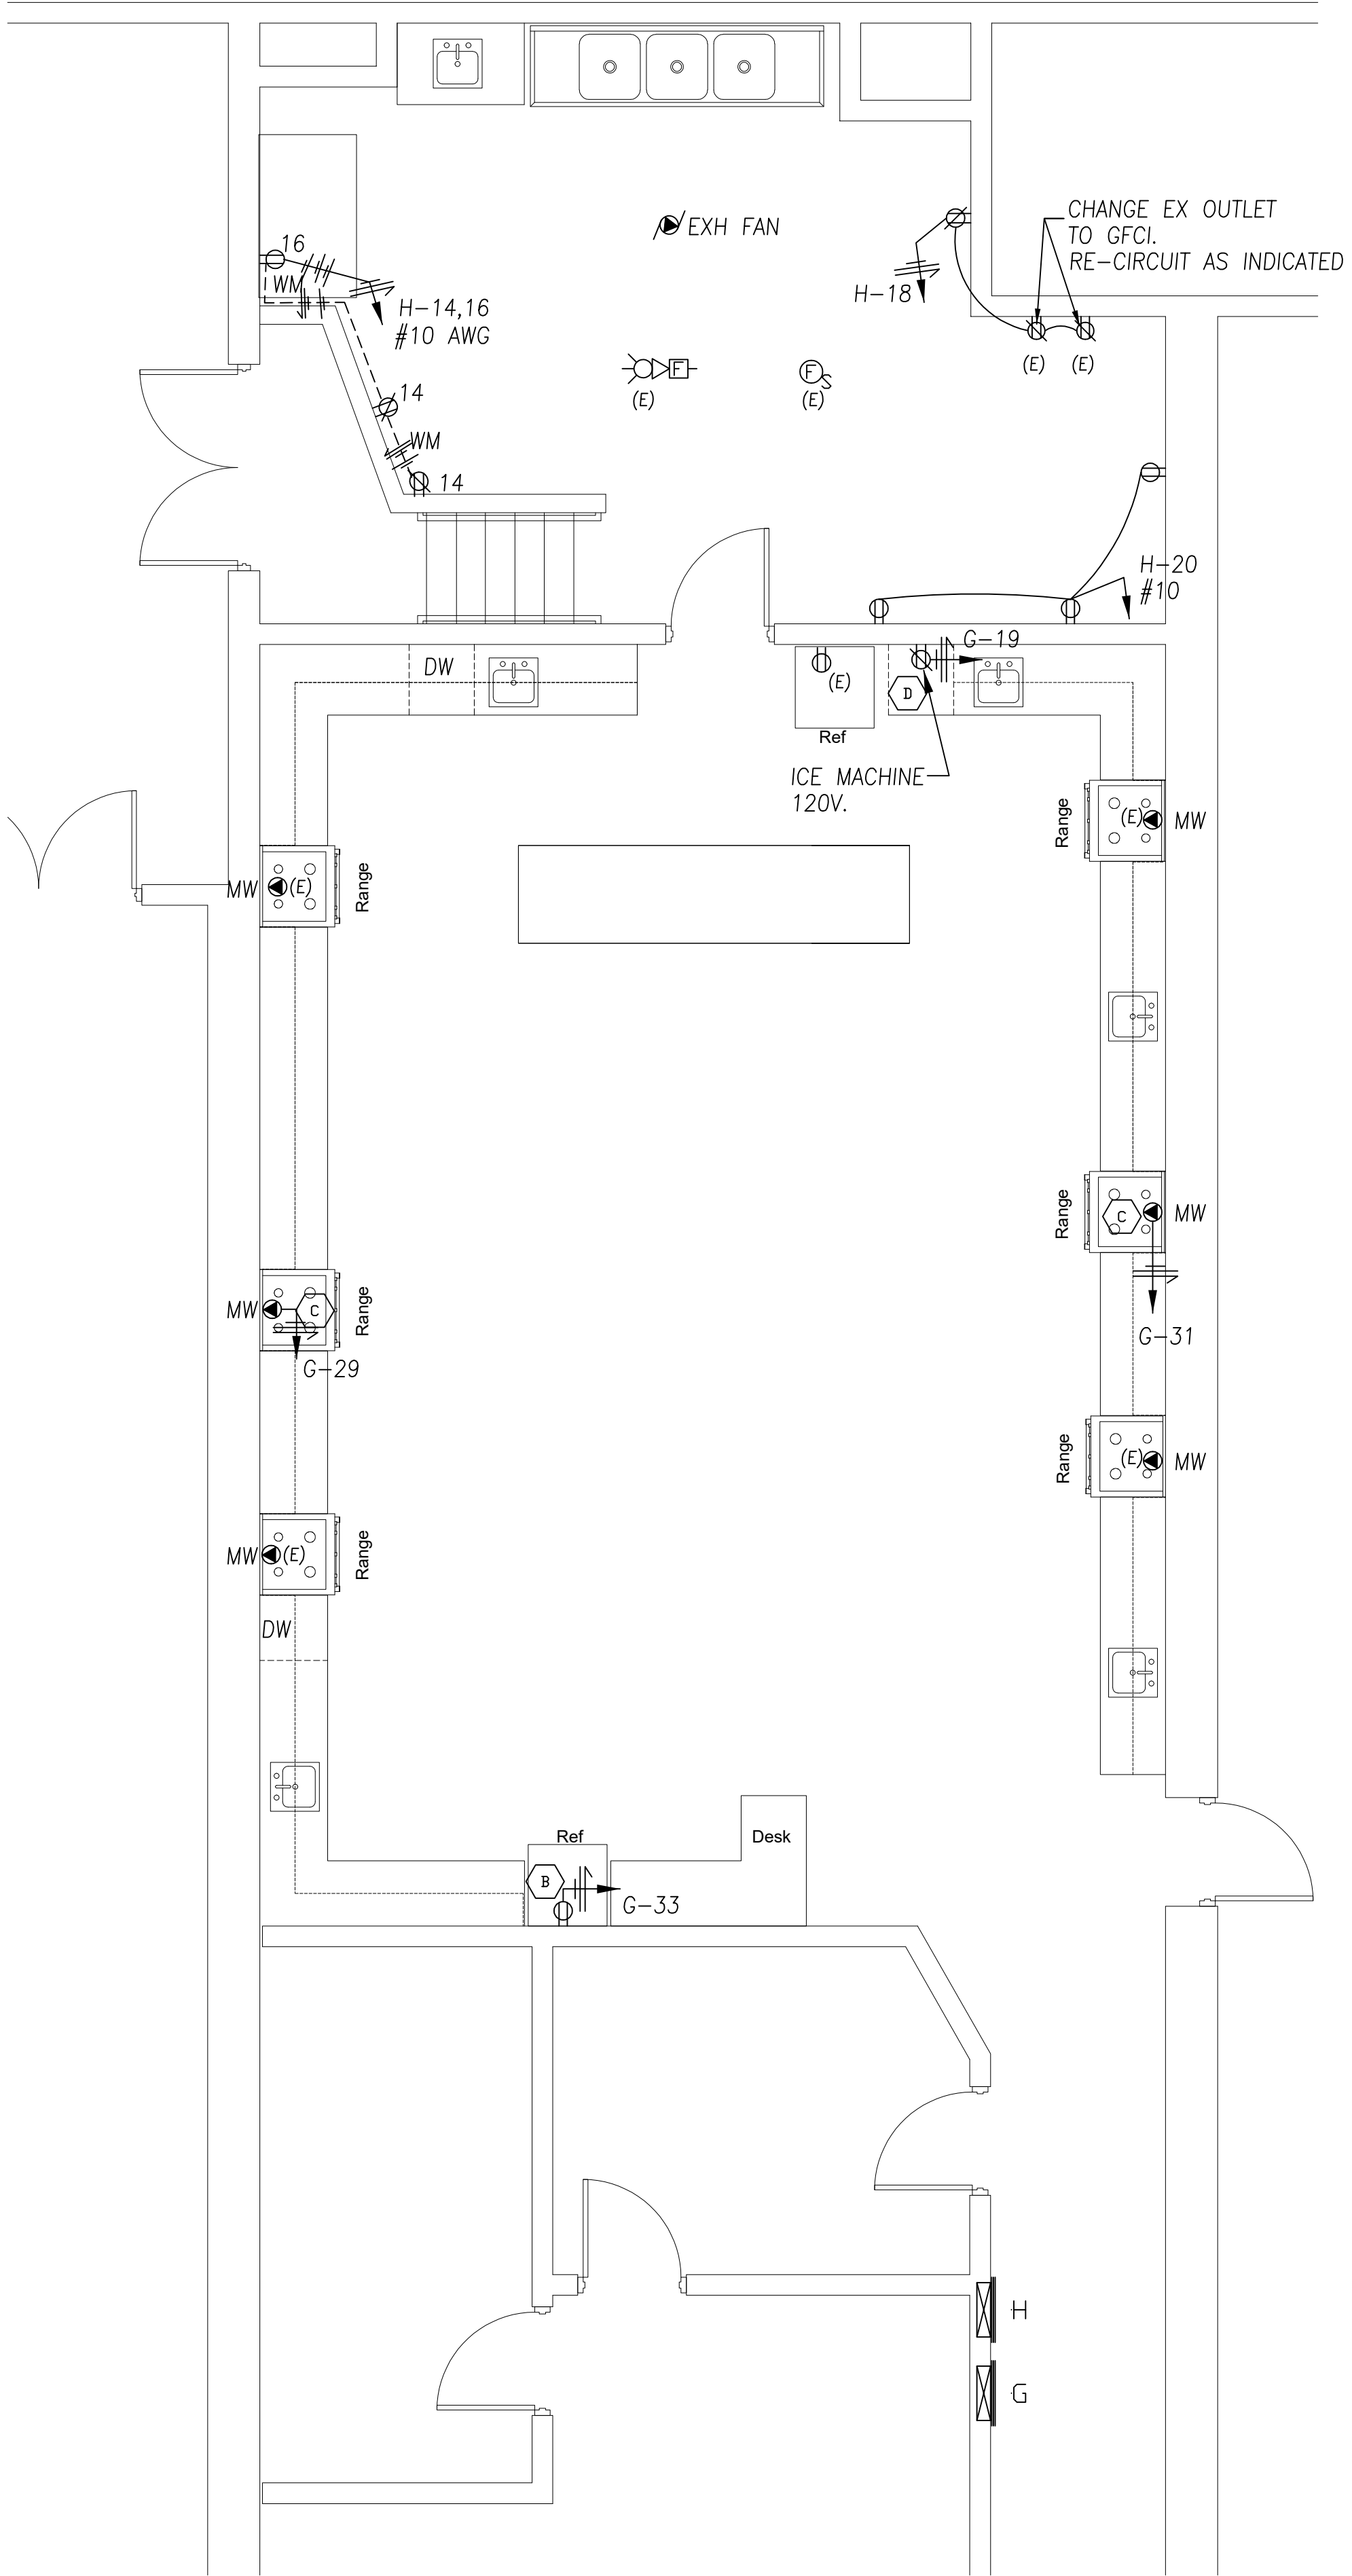

2 FIRST FLOOR POWER PLAN
E2.0 SCALE: 1/4" = 1'-0"


A&A

ATHAY & ASSOC.
INC.
CONSULTING
ELECTRICAL ENGINEERS
13023 NE HWY 99 Ste 7 #248
VANCOUVER, WA 98686
(360) 608-8285
rathay@athayeng.com

Revision Schedule		

COLLINS

ARCHITECTURAL GROUP, P.S.
950 12th AVE, SUITE 200
LONGVIEW, WA 98632
PHONE: 360-425-0000
E-MAIL: craige@collinsarchgroup.com

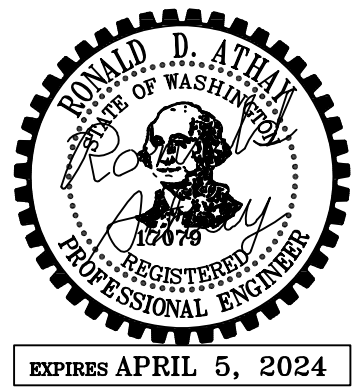

LPS - RA LONG
KITCHEN REMODEL
2903 NICHOLS BLVD, LONGVIEW, WA 98632

PERMIT SET
6-23-2023

FIRST FLOOR
PWR/LIGHTING

2020-03
SHEET NO.

E2.0