Addendum 3

Project Stadium New Press Box – Marlin ISD

Issued February 1st, 2024 by CEI Engineering Associates, Inc.

Proposal Opening February 6th, 2024 at 2:00 PM

The following additions and changes are to be made to the Contract Documents; and hereby become part of the Contract.

Item 1 – Press Box Electrical Scope Clarification

1. Sheet E6.01 – Electrical Site Plan has had its notes revised to clearly indicate the scope of this project.

Changes include clarification regarding what portions of the work at the stadium are to be included as part of this proposal and which are to be performed by others.

2. For clarification purposes, the scope of this project does not include any work in the parking lot area show on the stadium site plan. That work will be preformed by others. Also, the new scoreboard will be provided and installed by others.

END OF ADDENDUM

This addendum that consists of one (1) addenda sheet and one (1) drawing sheet which shall be included as part of the proposal documents.


This addenda and Addendum No1 & Addendum No.2 must be acknowledged on the Proposal Form




Torel

06/01/24

Addendum 3 – Marlin ISD Stadium New Press Box

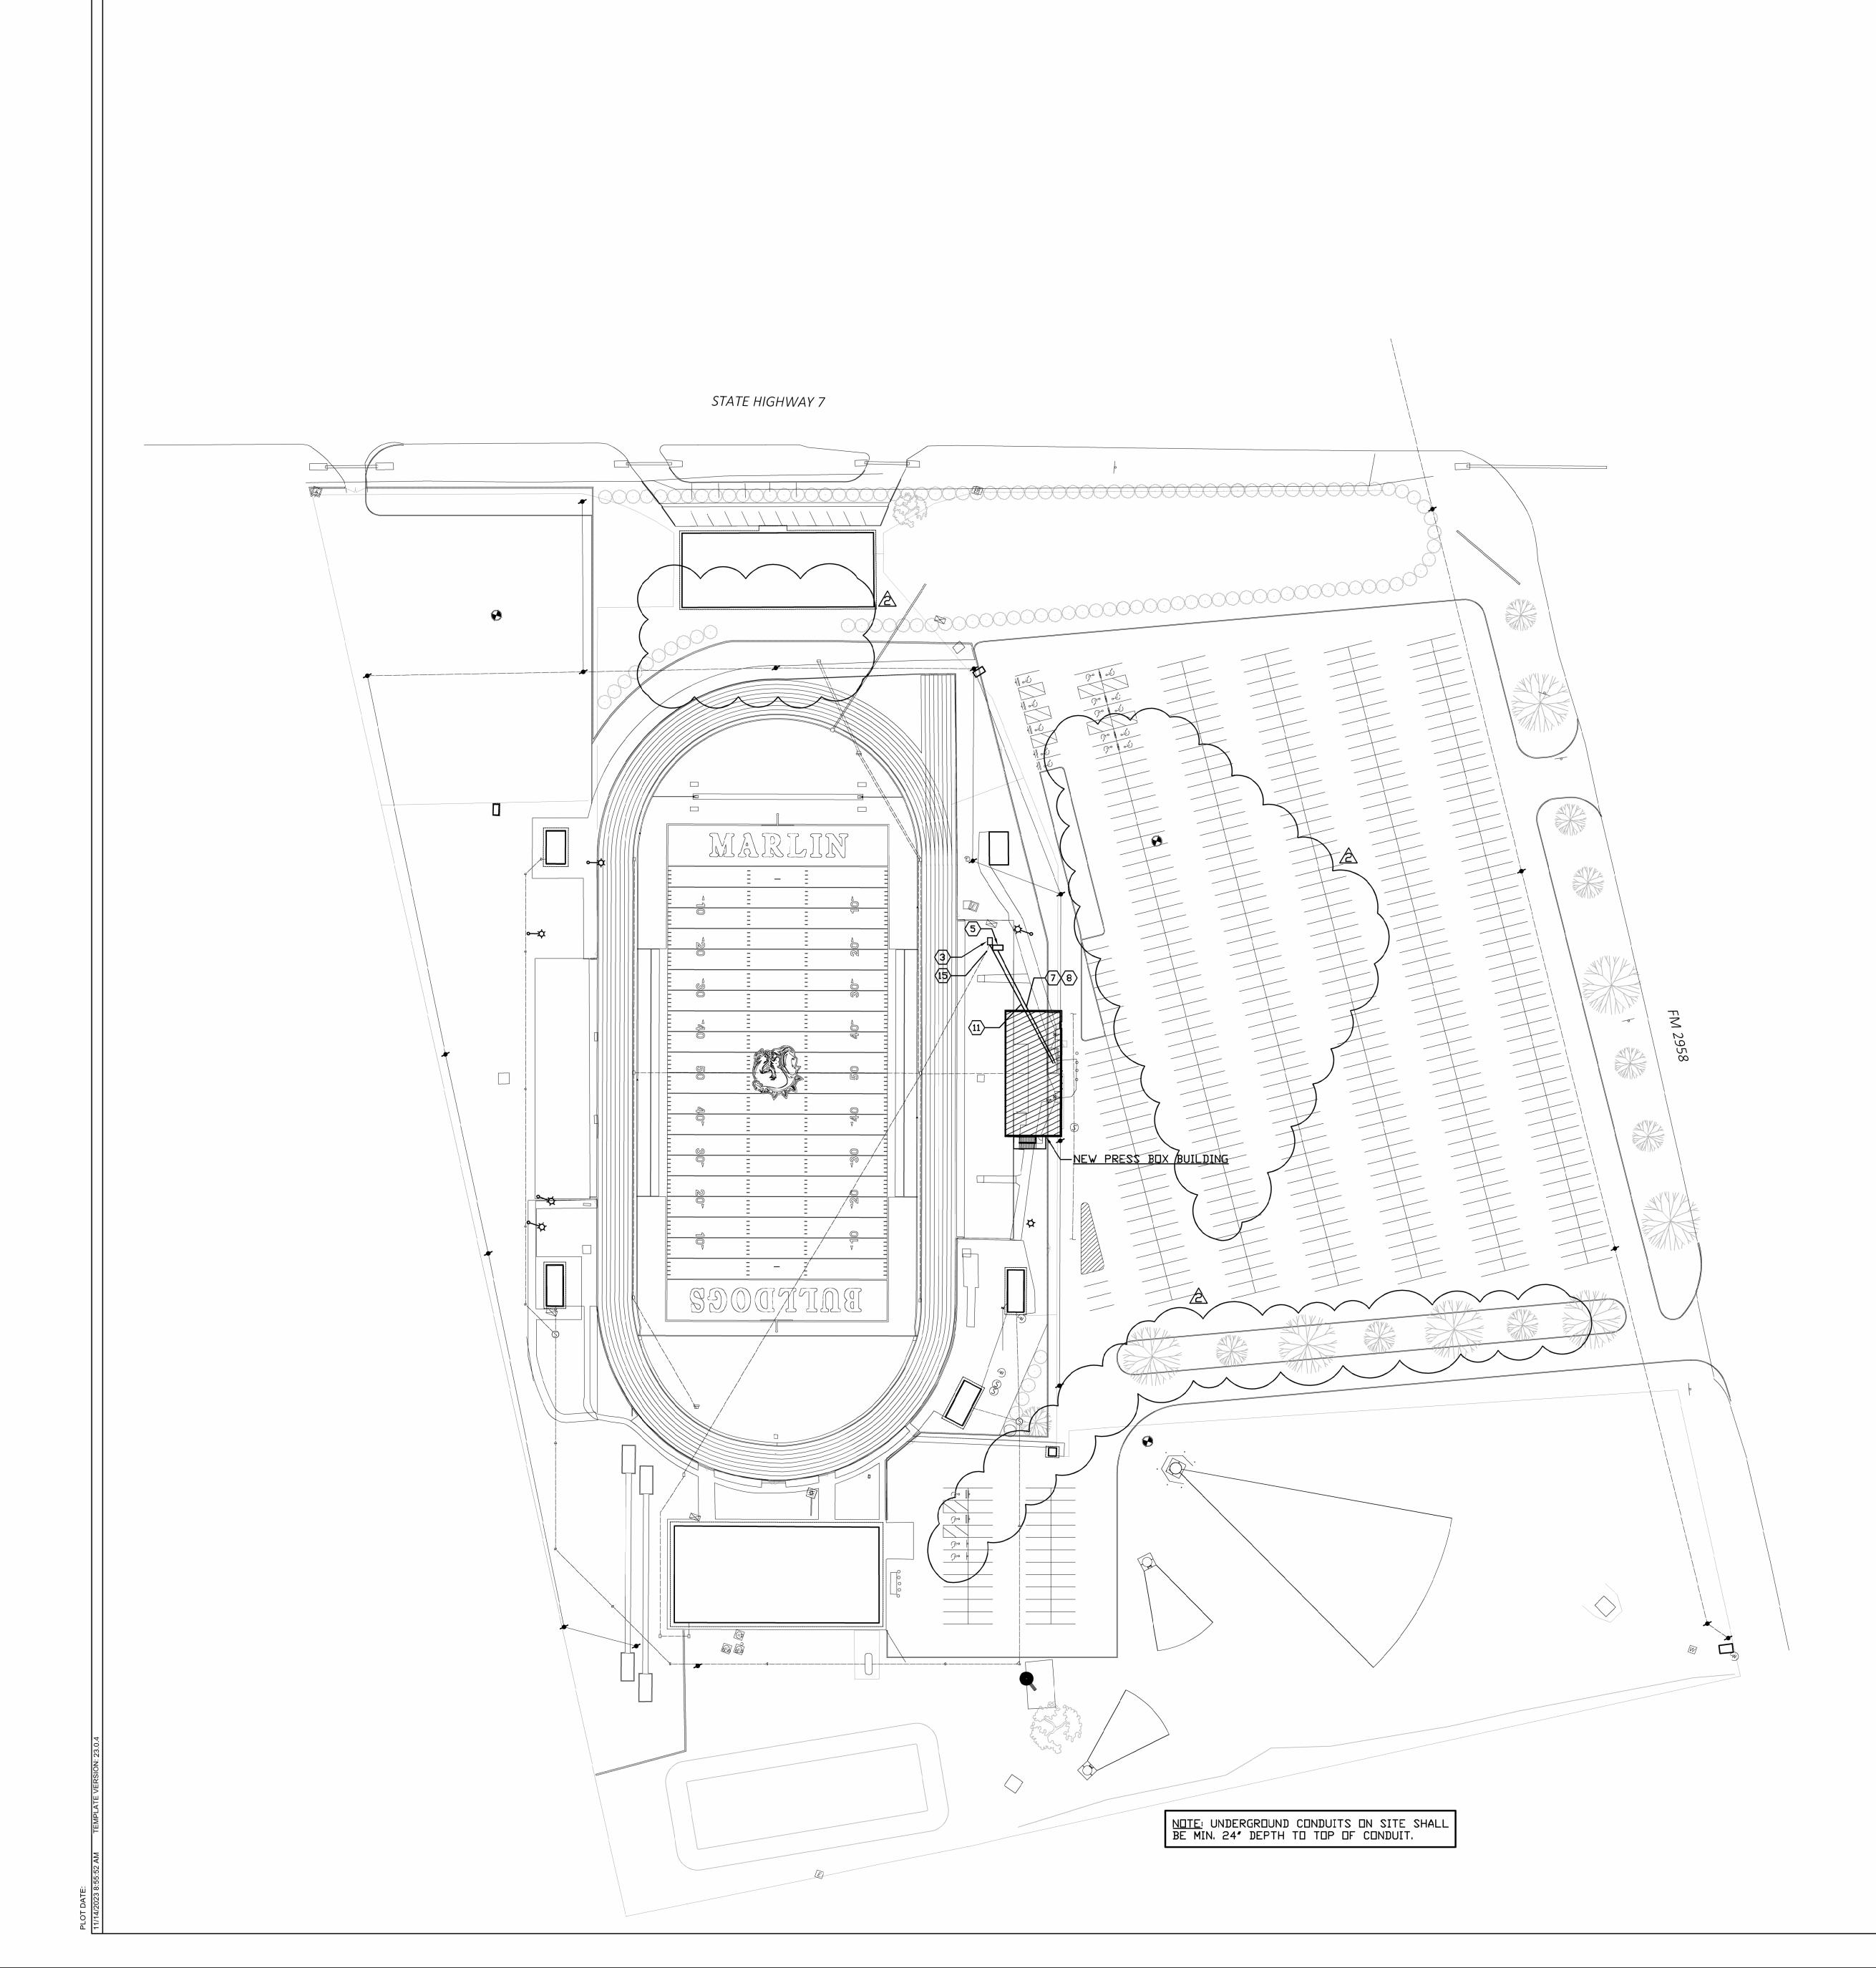

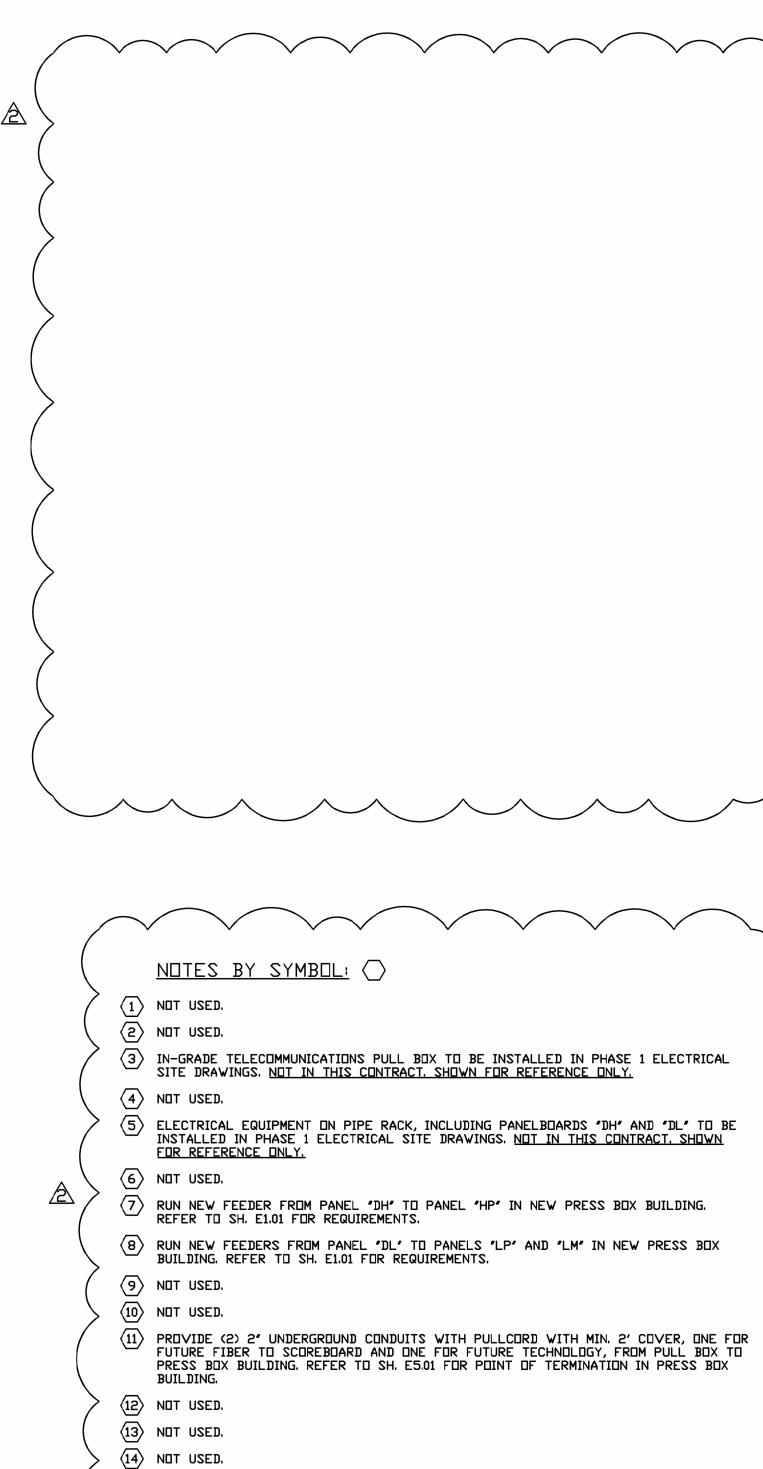





GENERAL NOTES:

A. UNDERGROUND CONDUITS SHALL BE BURIED WITH MINIMUM 24" COVER. REFER TO SPECIFICATIONS FOR SPECIFIC INSTALLATION REQUIREMENTS. B. VERIFY LOCATION OF ALL UNDERGROUND UTILITIES IN CONSTRUCTION AREA PRIOR TO BORING OR DIGGING.

C. SAWCUT AND REPAIR SIDEWALKS AND PAVED AREAS AS/IF REQUIRED TO ACCOMMODATE UNDERGROUND CONDUIT INSTALLATION. FIELD VERIFY EXISTING CONDITIONS PRIOR TO BID TO DETERMINE MOST FEASIBLE ROUTING OF ALL ELECTRICAL FEEDERS AND COMPLETE SCOPE OF WORK.

D. TWO OR MORE CIRCUITS MAY BE COMBINED IN ONE CONDUIT AT DISCRETION OF CONTRACTOR AS LONG AS INDICATED CONDUIT SIZE IS INCREASED PER NEC REQUIREMENTS. E. REFER TO ELECTRICAL SPECIFICATIONS FOR IN-GRADE JUNCTION BOX REQUIREMENTS. PROVIDE BOXES WHERE REQUIRED TO FACILITATE LONG WIRE PULLS.

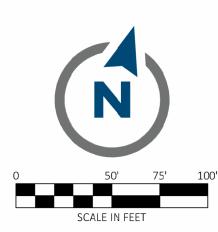

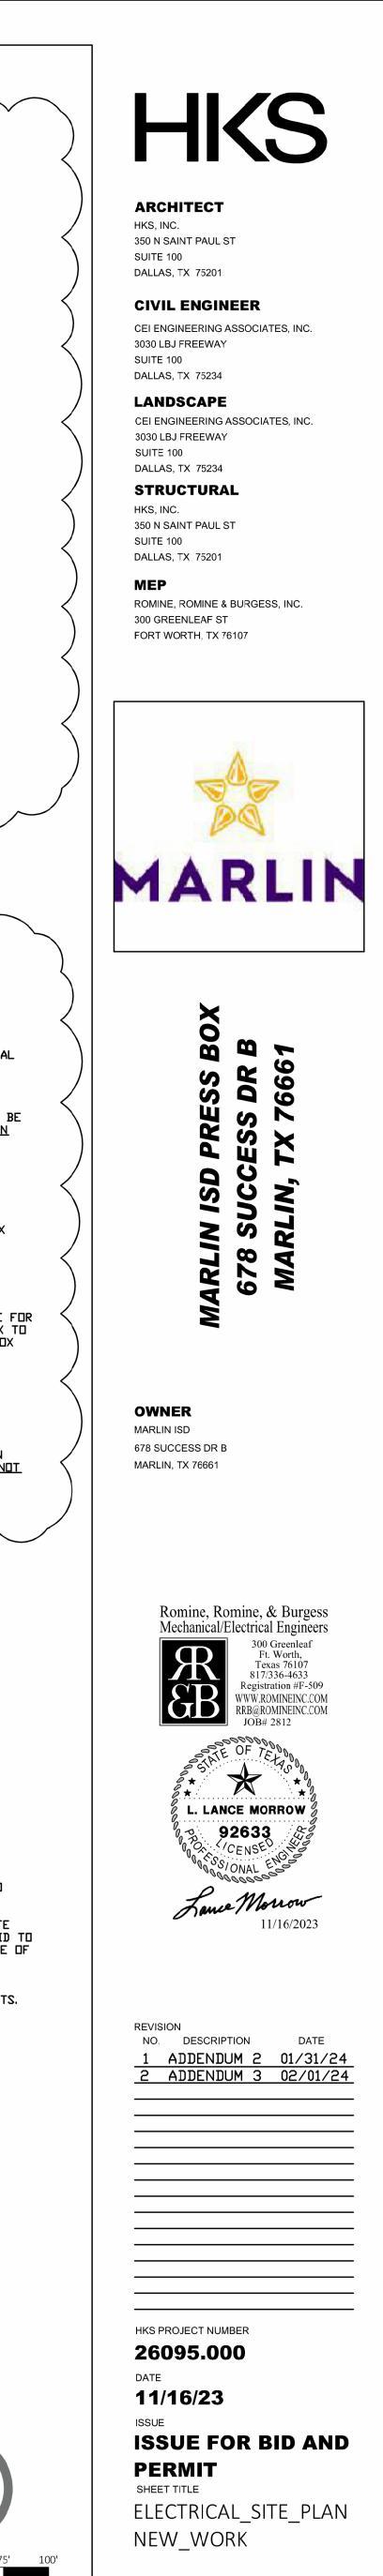

© 2019 HKS, INC.

SHEET NO.

E6.01