



2023-10-11 12:03:19 PM
Copyright 2015, Newman Architecture, Inc.
A2-0_Site Plan 2436.dwg
DWG: A2-0_Site Plan 2436.dwg
newman.ai

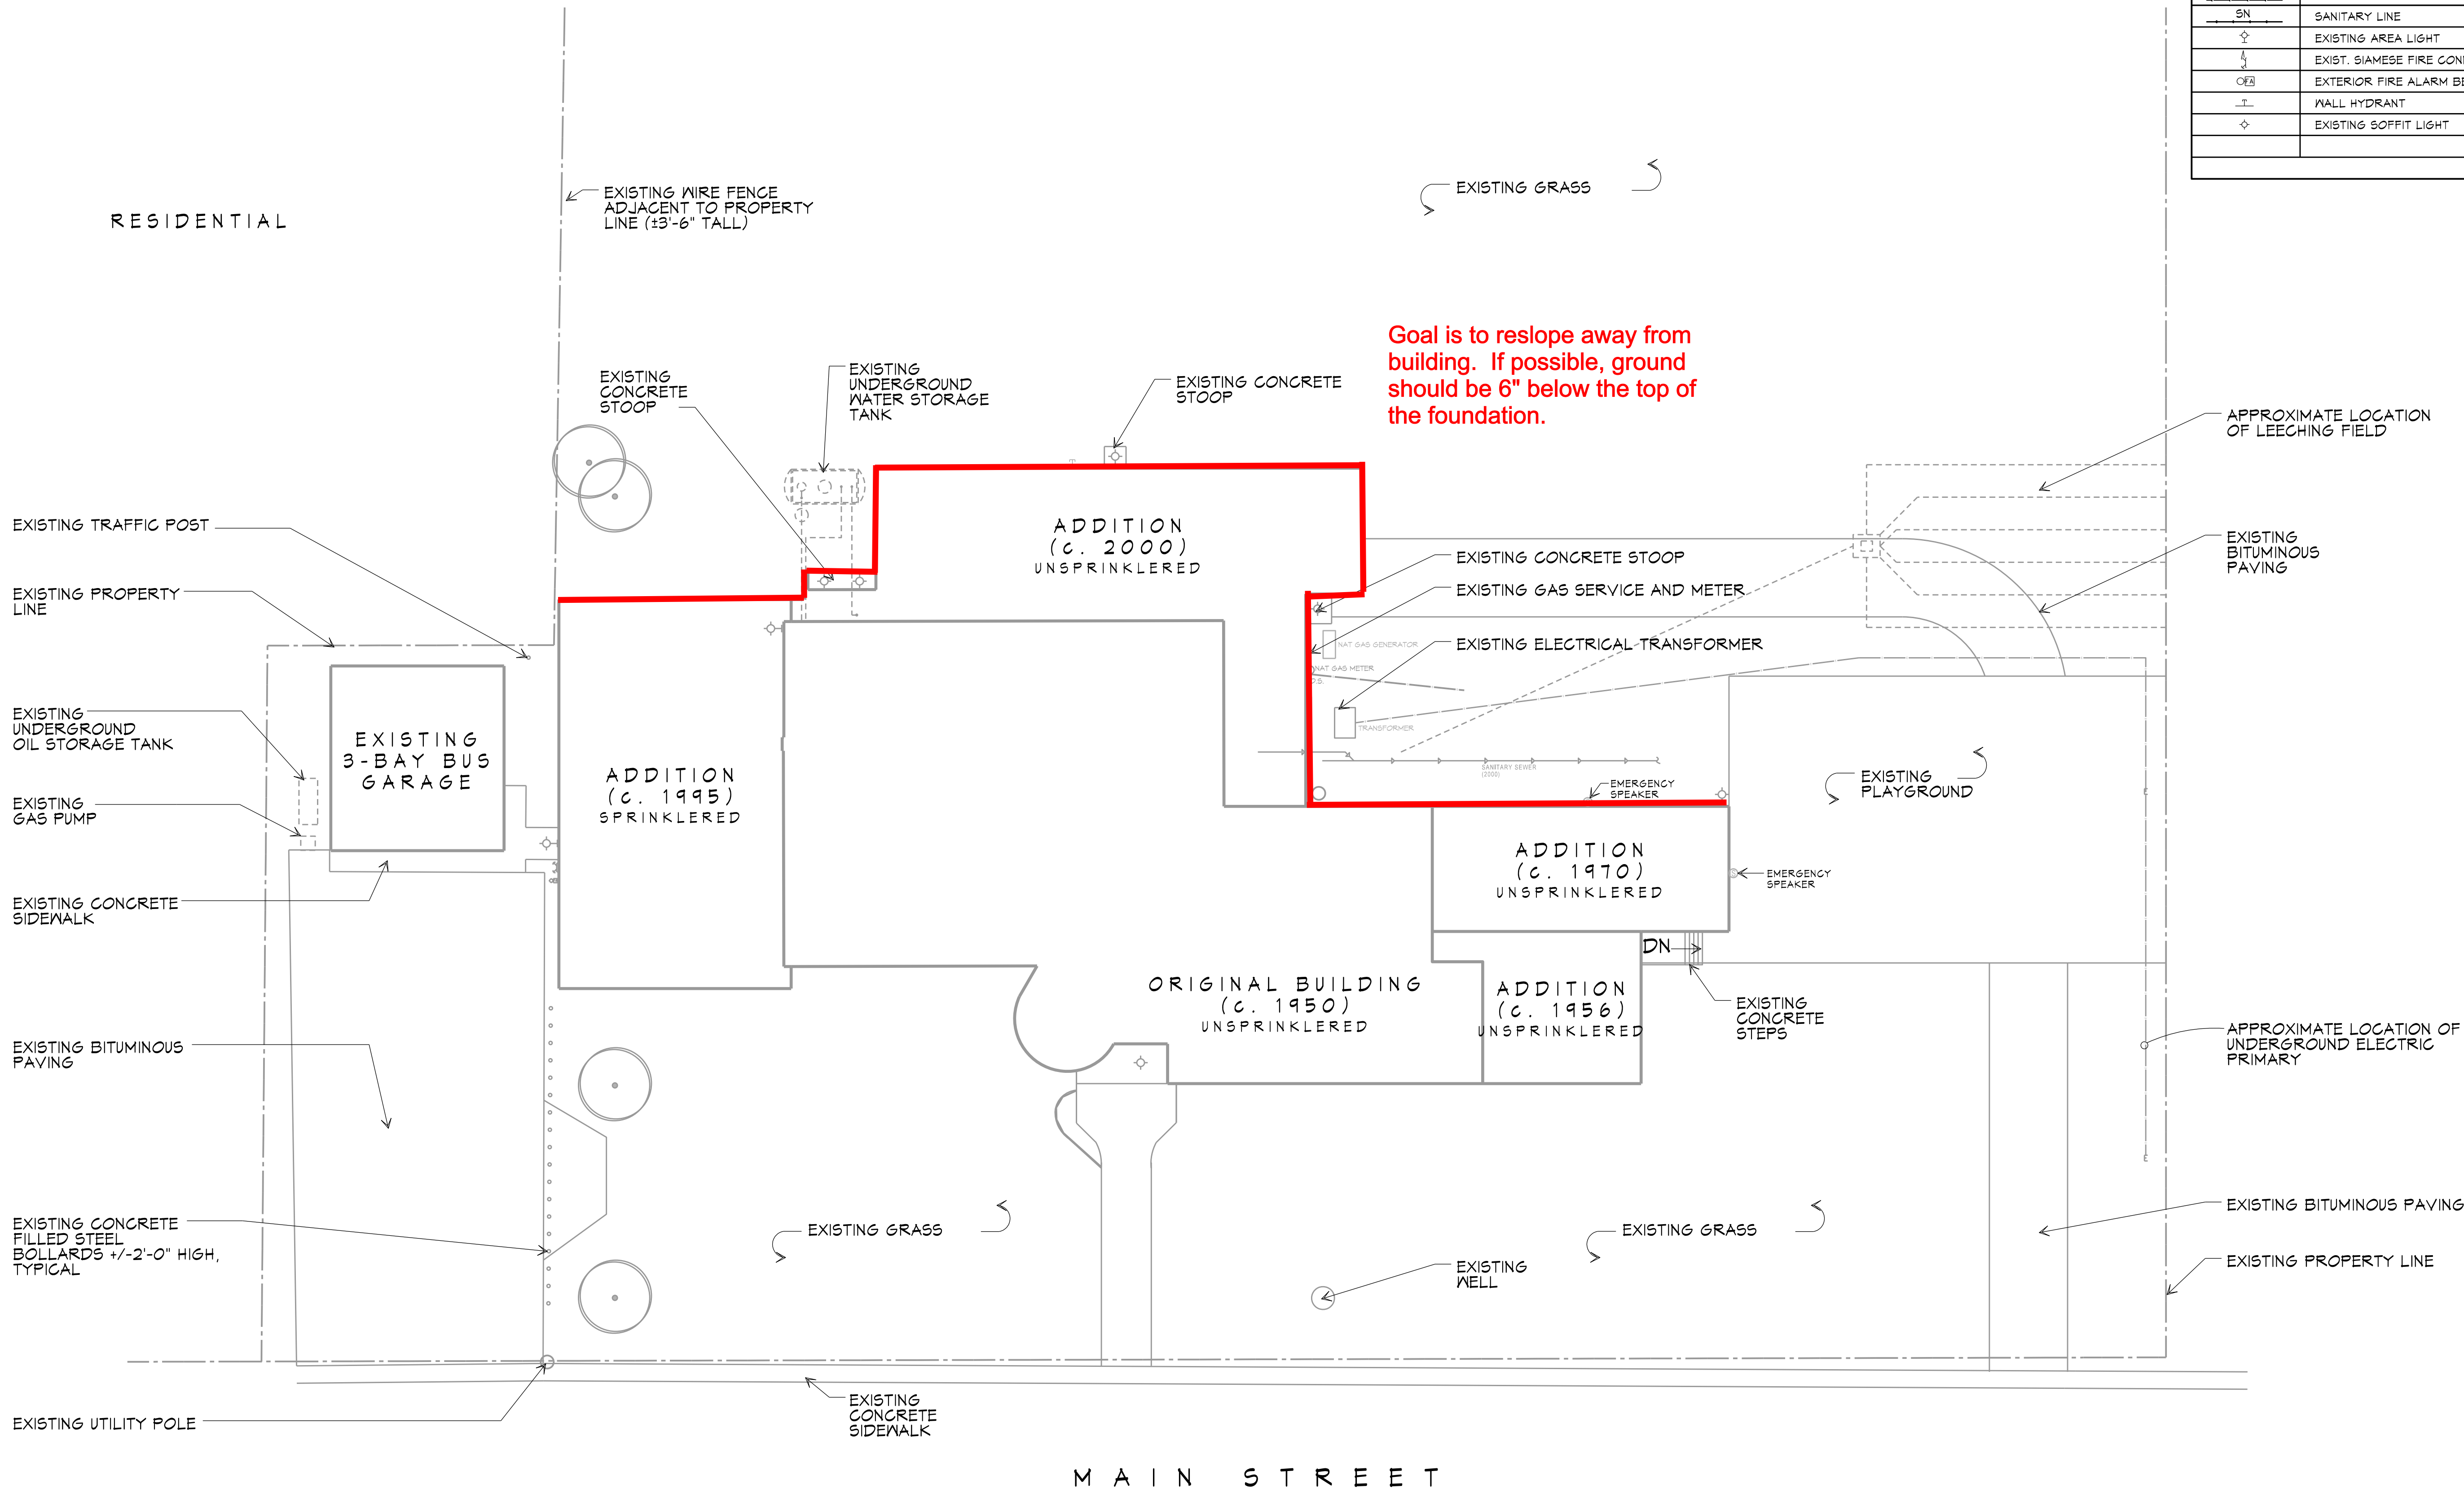

SYMBOL LEGEND	
SYMBOL	DESCRIPTION
---	PROPERTY LINE
- - - -	OVERHEAD ELECTRICAL WIRES
■	UTILITY POLE
⋈	FIRE HYDRANT
W	WATER SUPPLY
G	GAS SUPPLY
E	ELECTRICAL SUPPLY
ST	STORM LINE
SN	SANITARY LINE
⊙	EXISTING AREA LIGHT
⋈	EXIST. SIAMESE FIRE CONNECTION
⊙	EXTERIOR FIRE ALARM BELL
+	WALL HYDRANT
⊙	EXISTING SOFFIT LIGHT

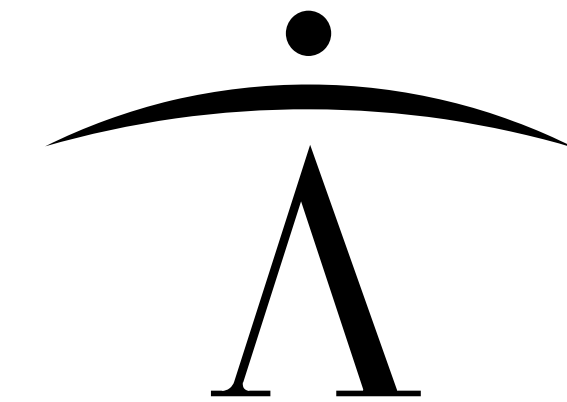

newman architecture
1730 Park Street, Suite 115, Naperville, Illinois 60563-2611
(630) 420-1600 FAX (630) 420-1987 www.newmanarchitecture.com

Project Name:

CONSTRUCTION DOCUMENTS

ESWOOD
SCHOOL

SITE DRAINAGE PLAN -
FALL 2022

ESWOOD ELEMENTARY SCHOOL
304 N. MAIN STREET
LINDENWOOD, ILLINOIS 61049

FOR
BOARD OF EDUCATION
ESWOOD CCSD 269

Architect's Certification:

License: Illinois Professional Design Firm
License No. 184-000549

Expires: 2023-04-30

License: Illinois Registration No. 001-009496

Expires: 2022-11-30

Signature *Charles R. Newman*

2022-10-10

Date

Drawing Title:

SITE LIFE SAFETY
REFERENCE PLAN

Issue/ Revision:

No.	Date	Description
-	2022-10-10	For Planning

Project Manager: CRN

Project No.: 2022053 Date: 2022-10-10

A2-0