
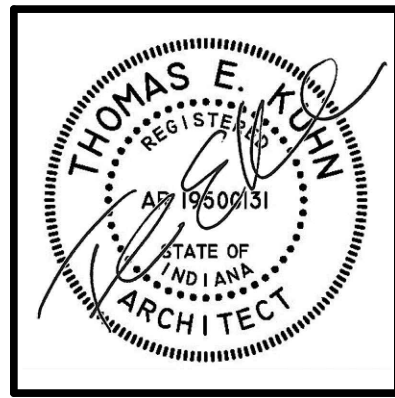
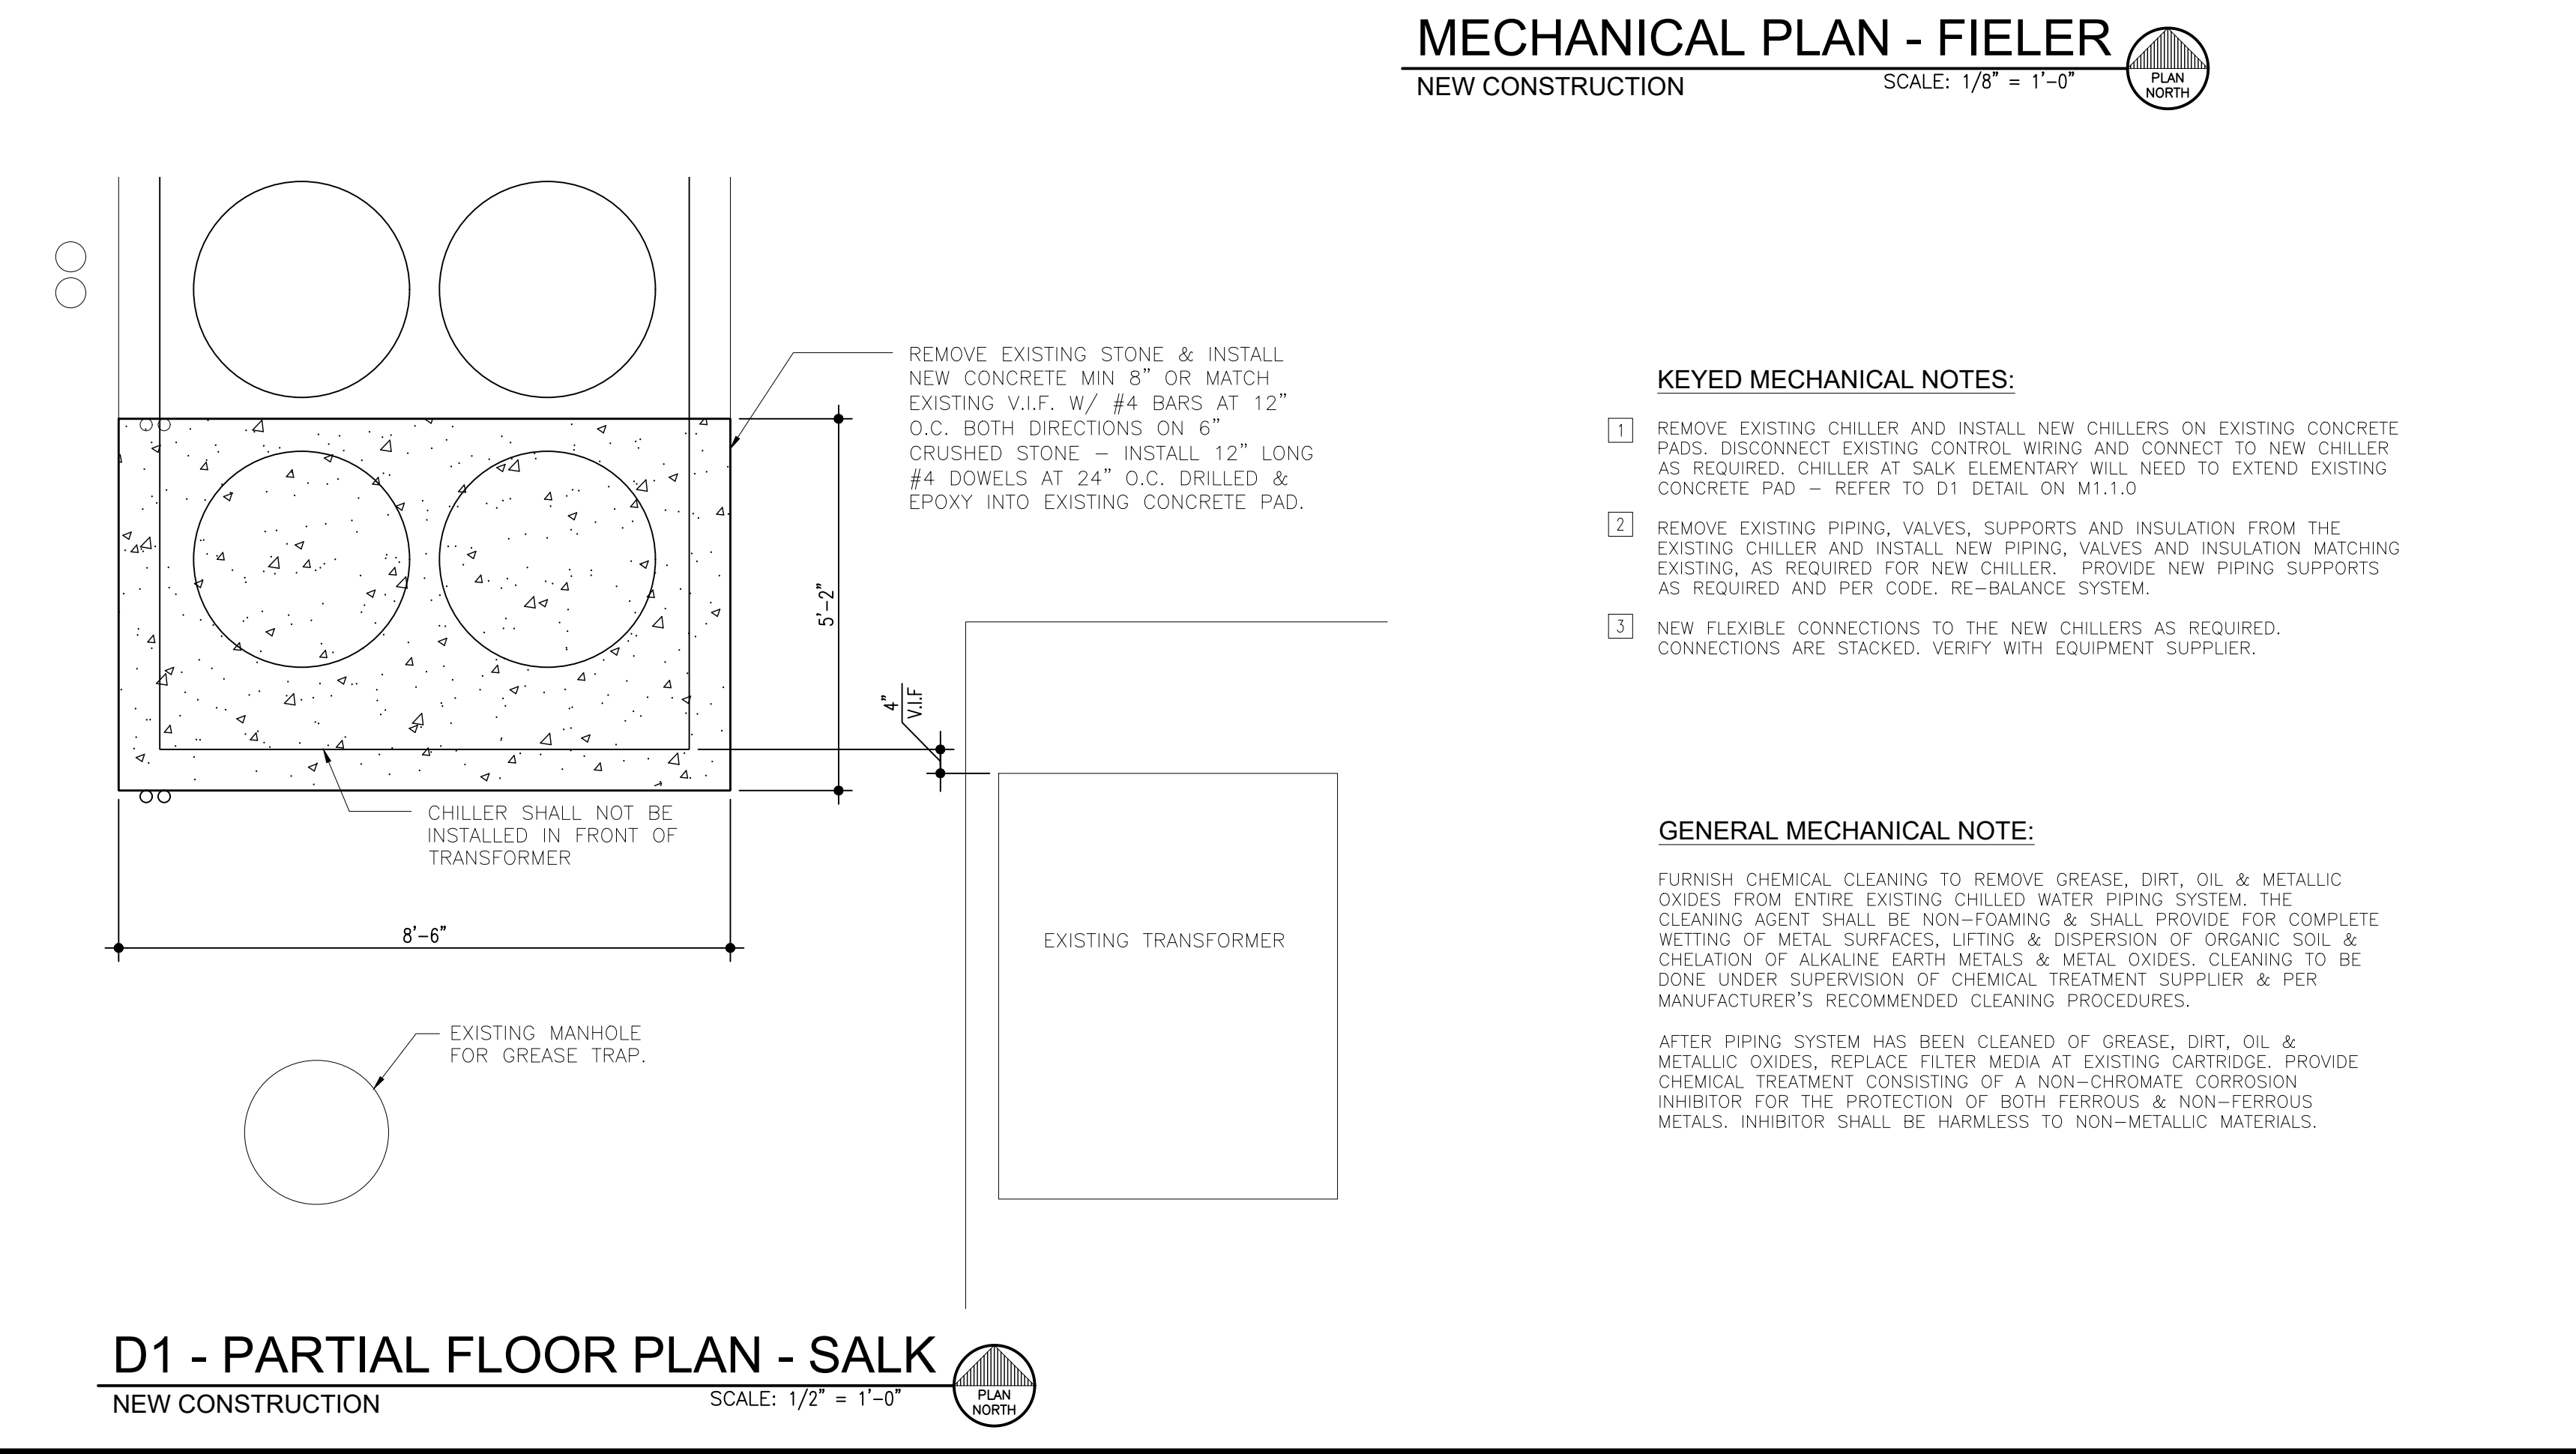
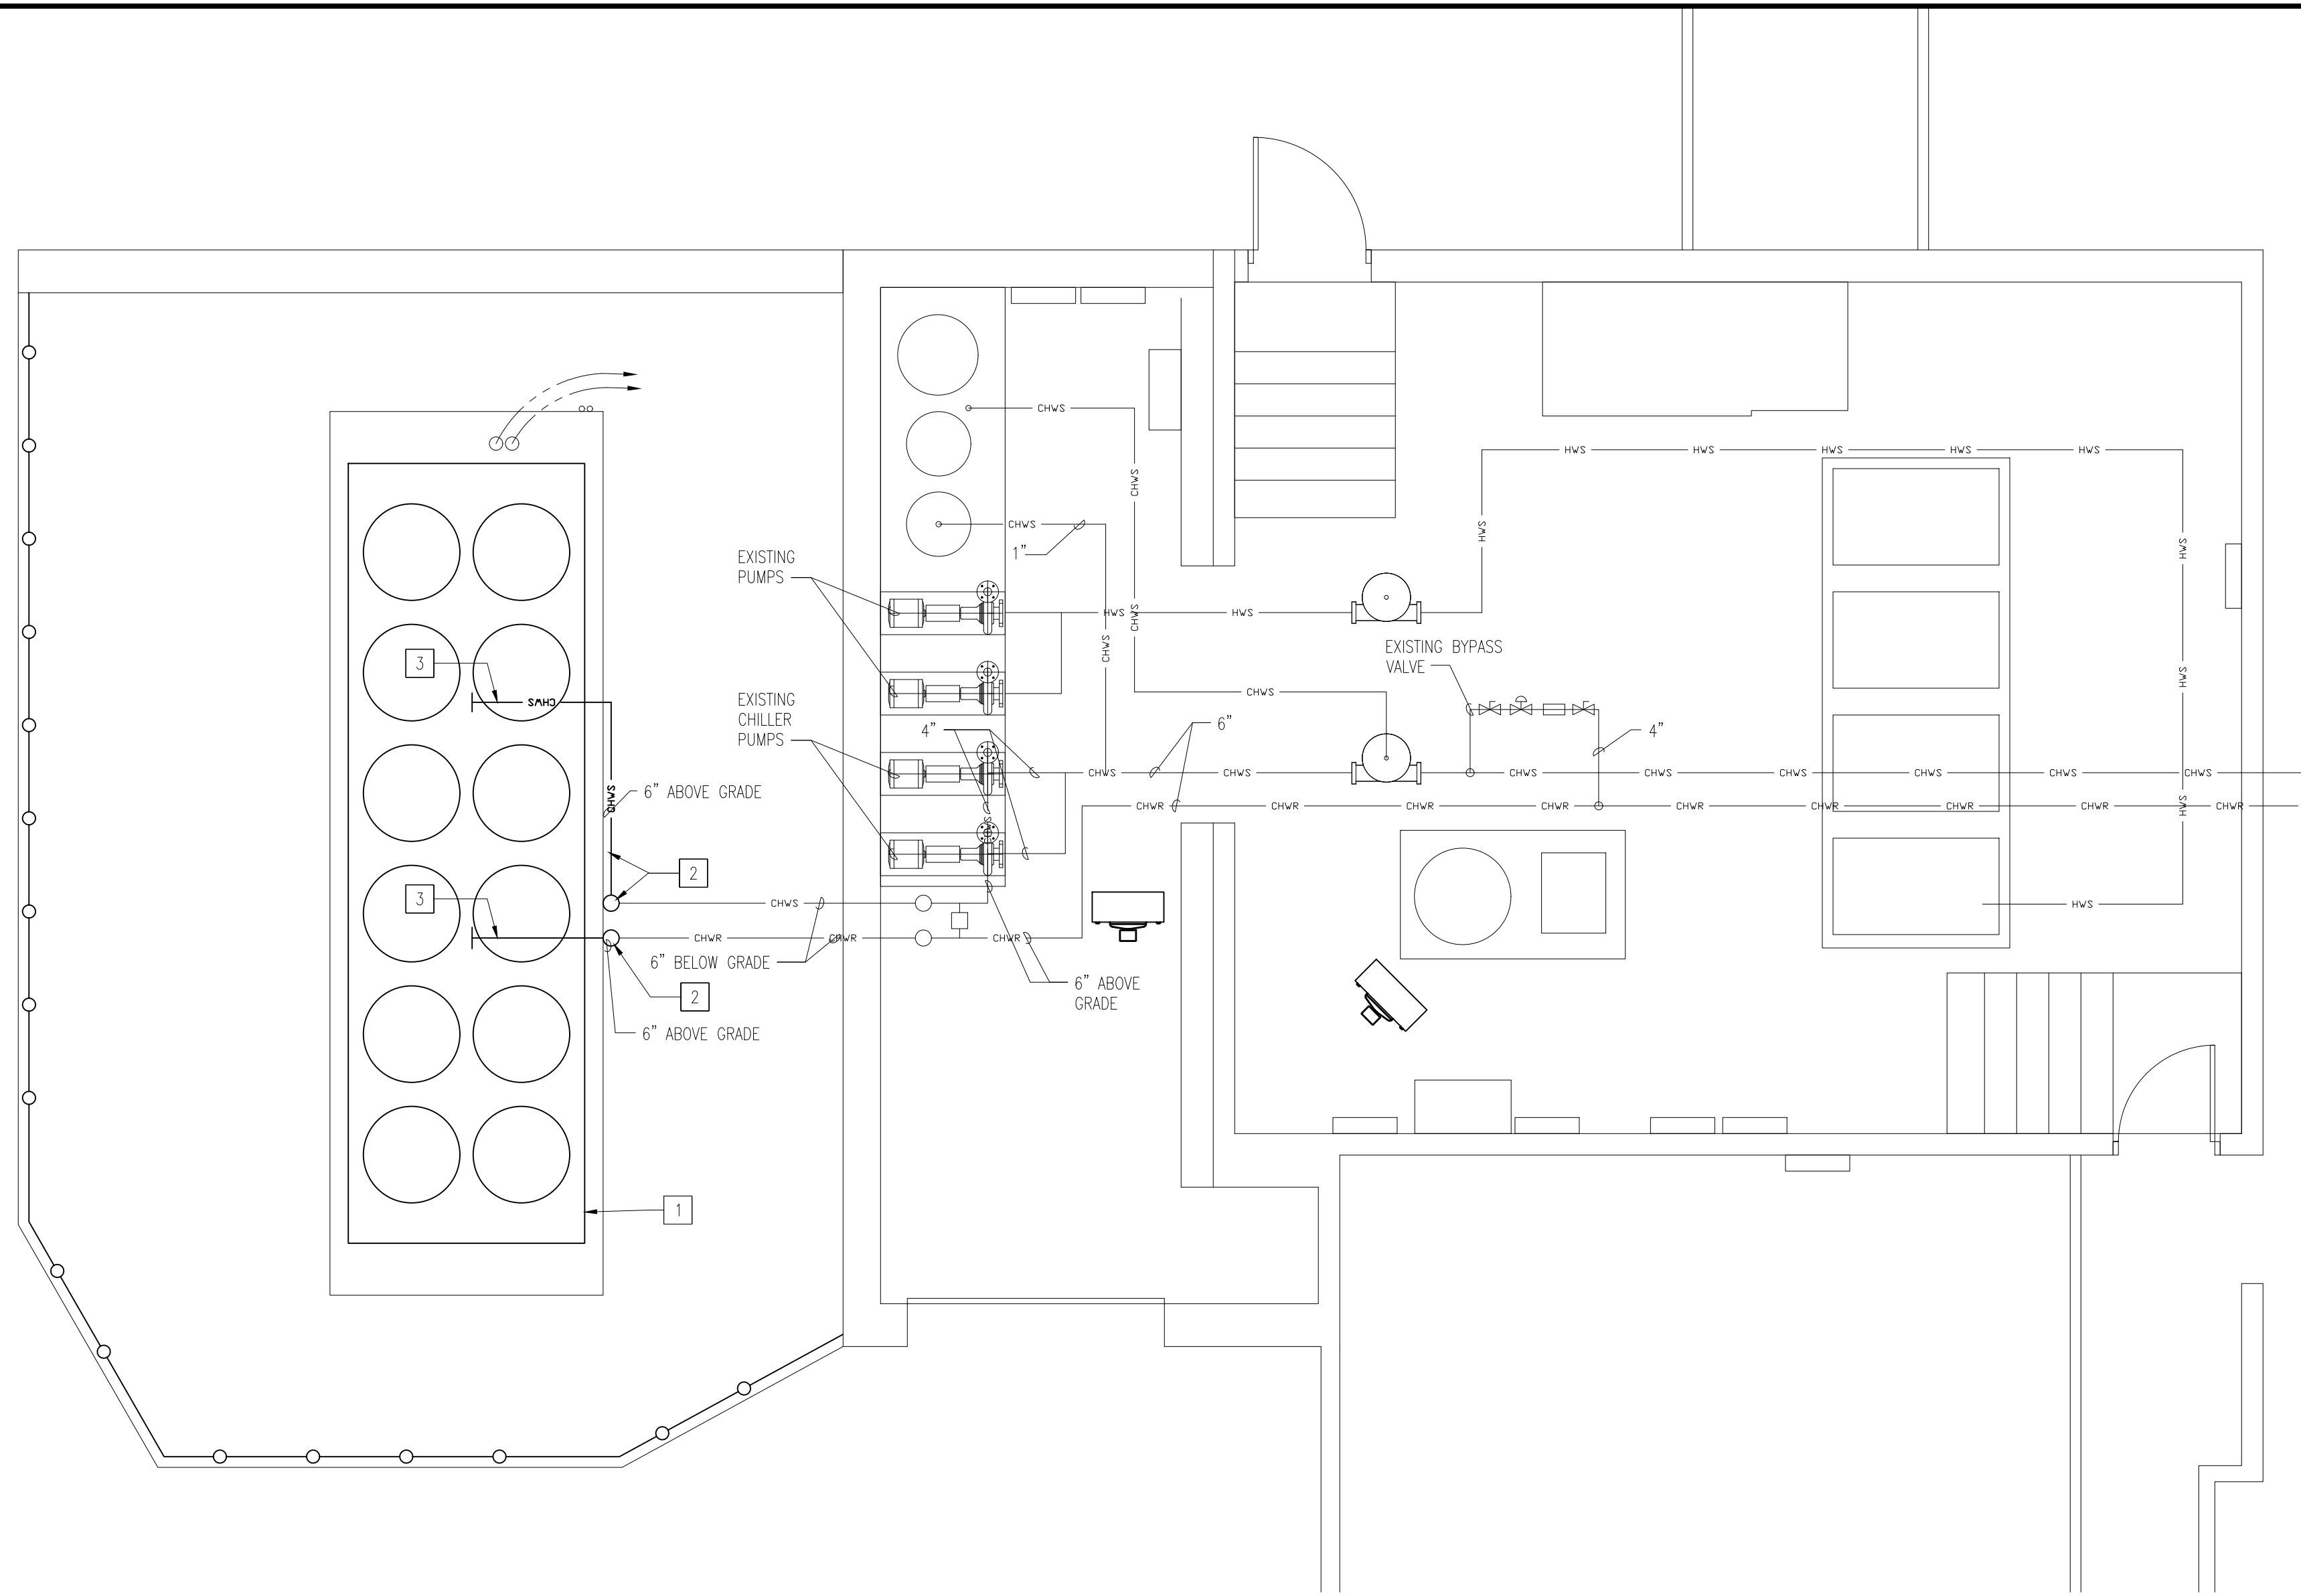


x:\merrillville schools\24012 chillers at fieler & salk\Drawings\m100 mechanical piping.dwg

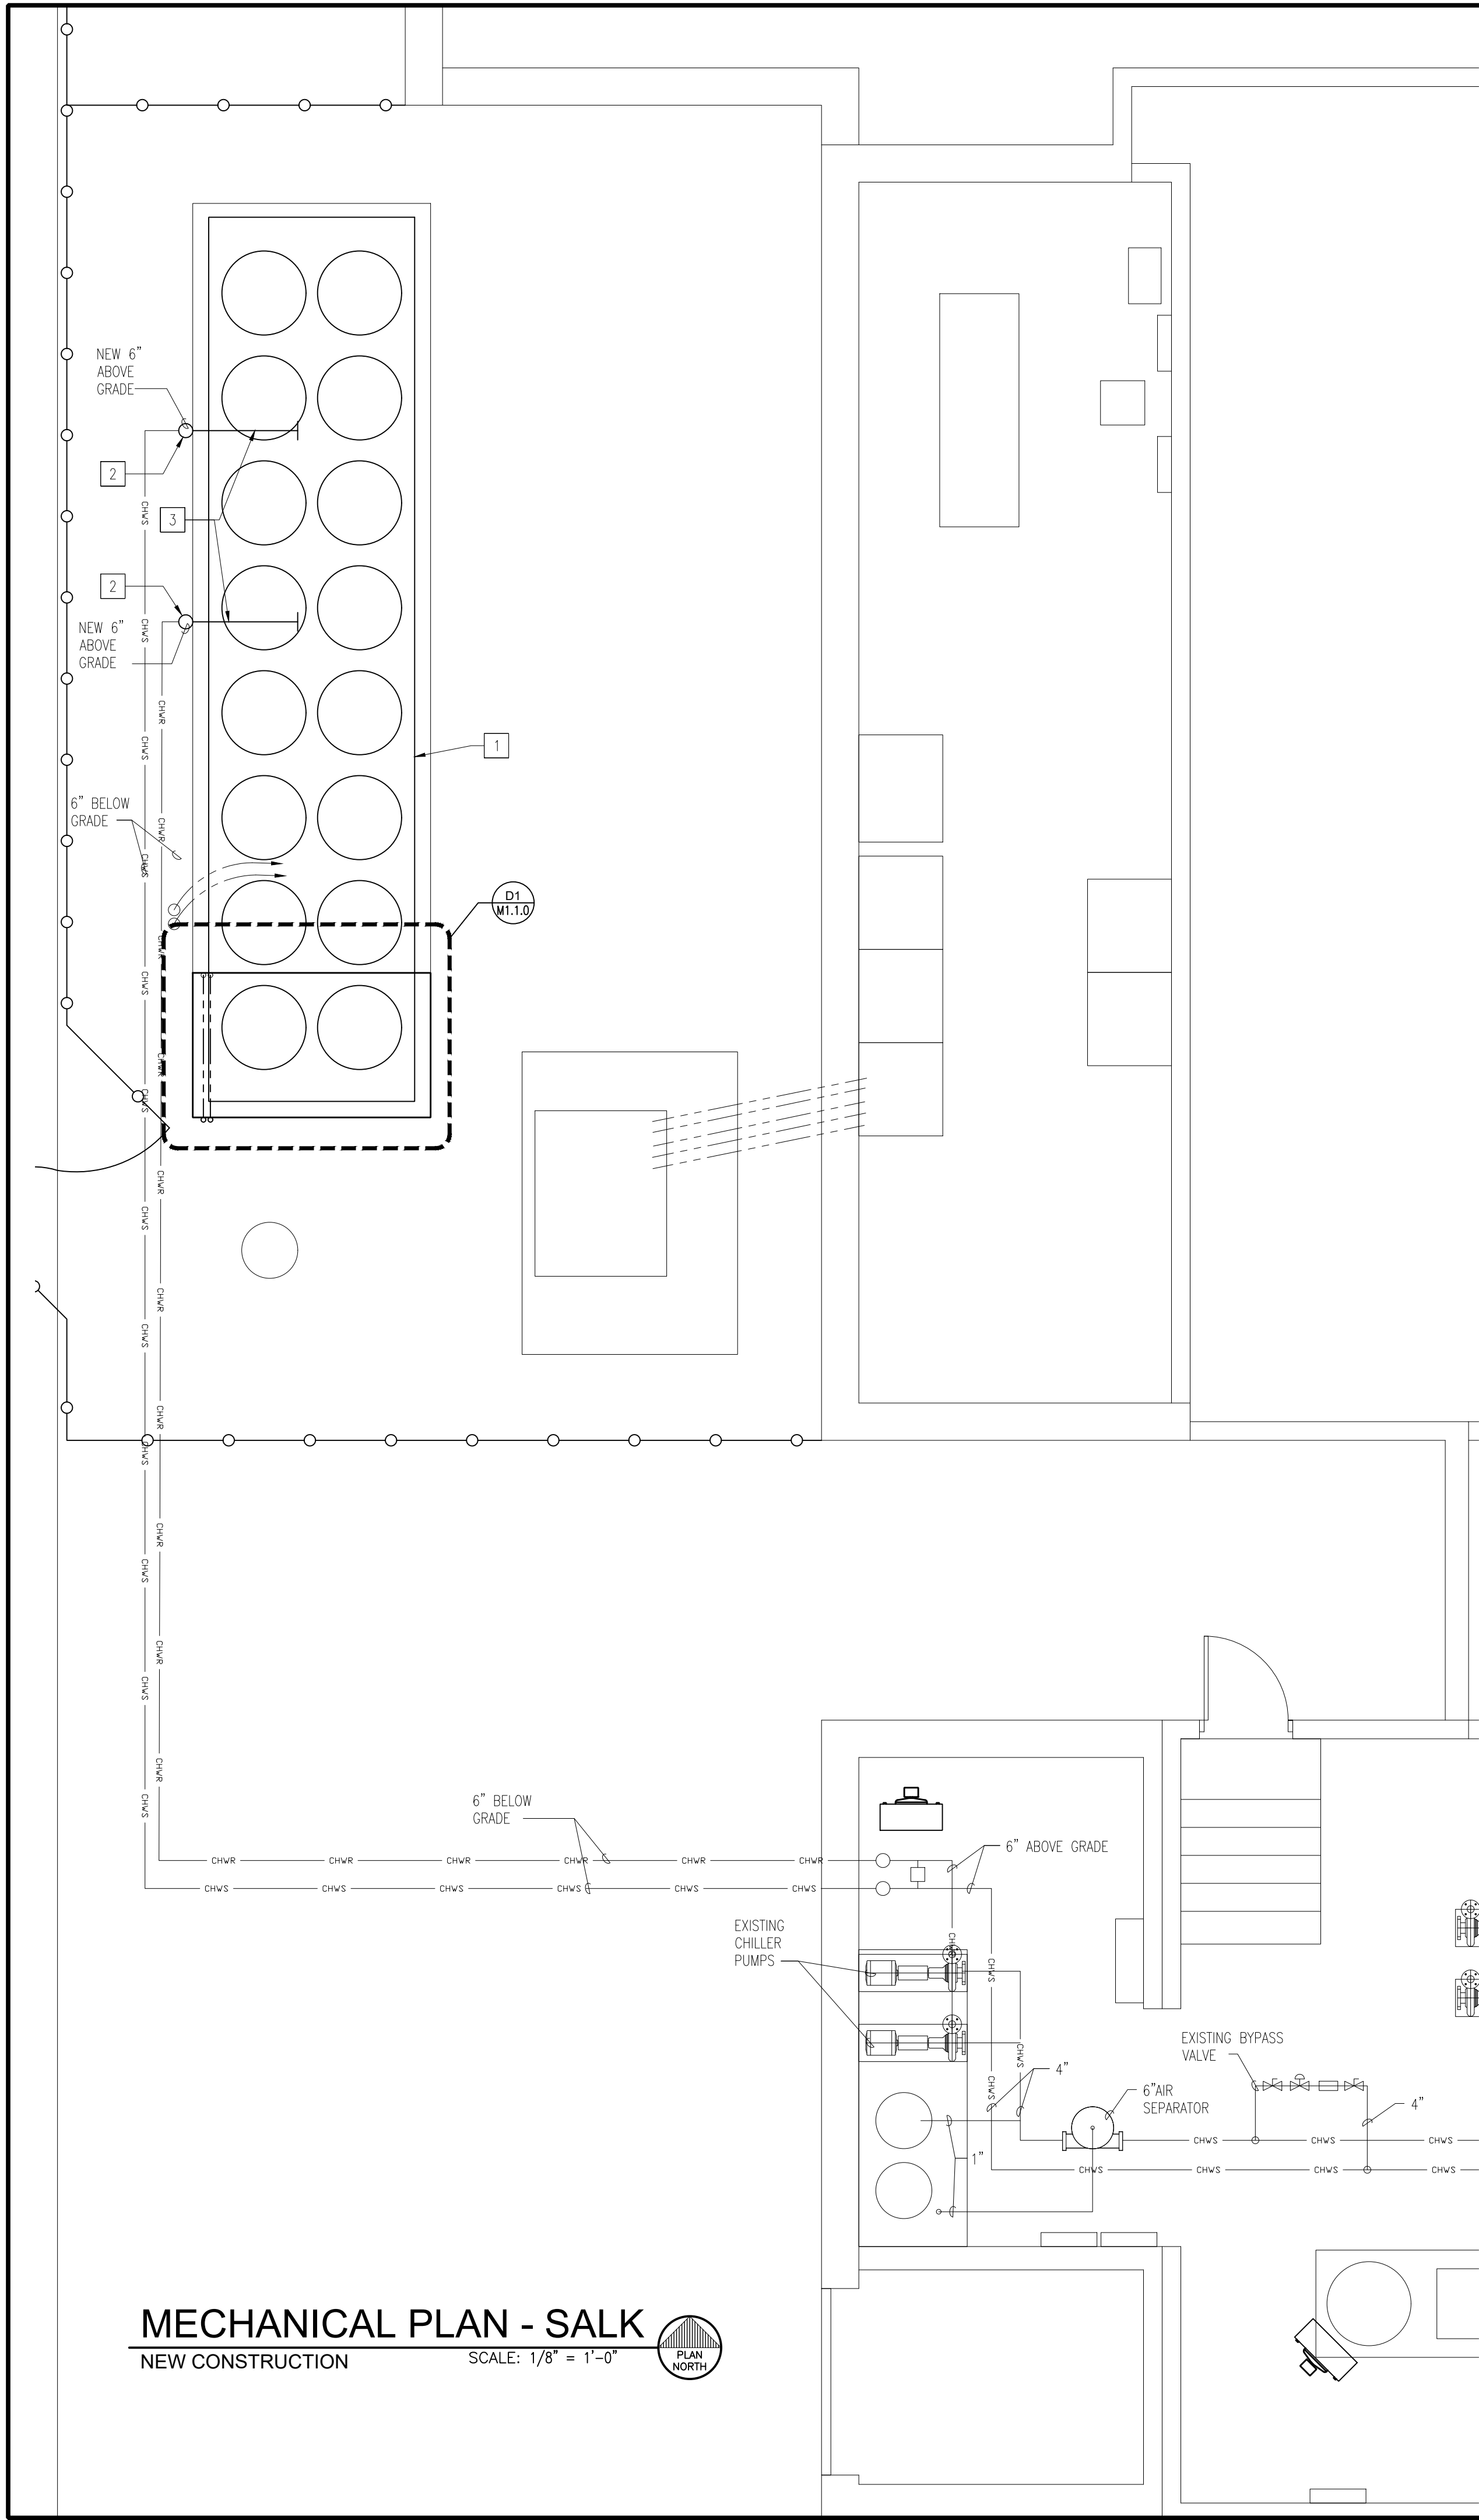

DATE
11/05/2024


CHILLER REPLACEMENT AT
SALK AND FIELER ELEMENTARY SCHOOL
FOR MERRILLVILLE COMMUNITY SCHOOL
6701 DELAWARE STREET
MERRILLVILLE, INDIANA 46410

CSK ARCHITECTS, P.C.
6919 W. LINCOLN HIGHWAY
219-322-5950
CROWN POINT, IN 46307
www.cskarchitects.com

24012

SHEET
1 OF 2

x:\merrillville schools\24012 chillers at fieler & salk\Drawings\m100 mechanical piping.dwg

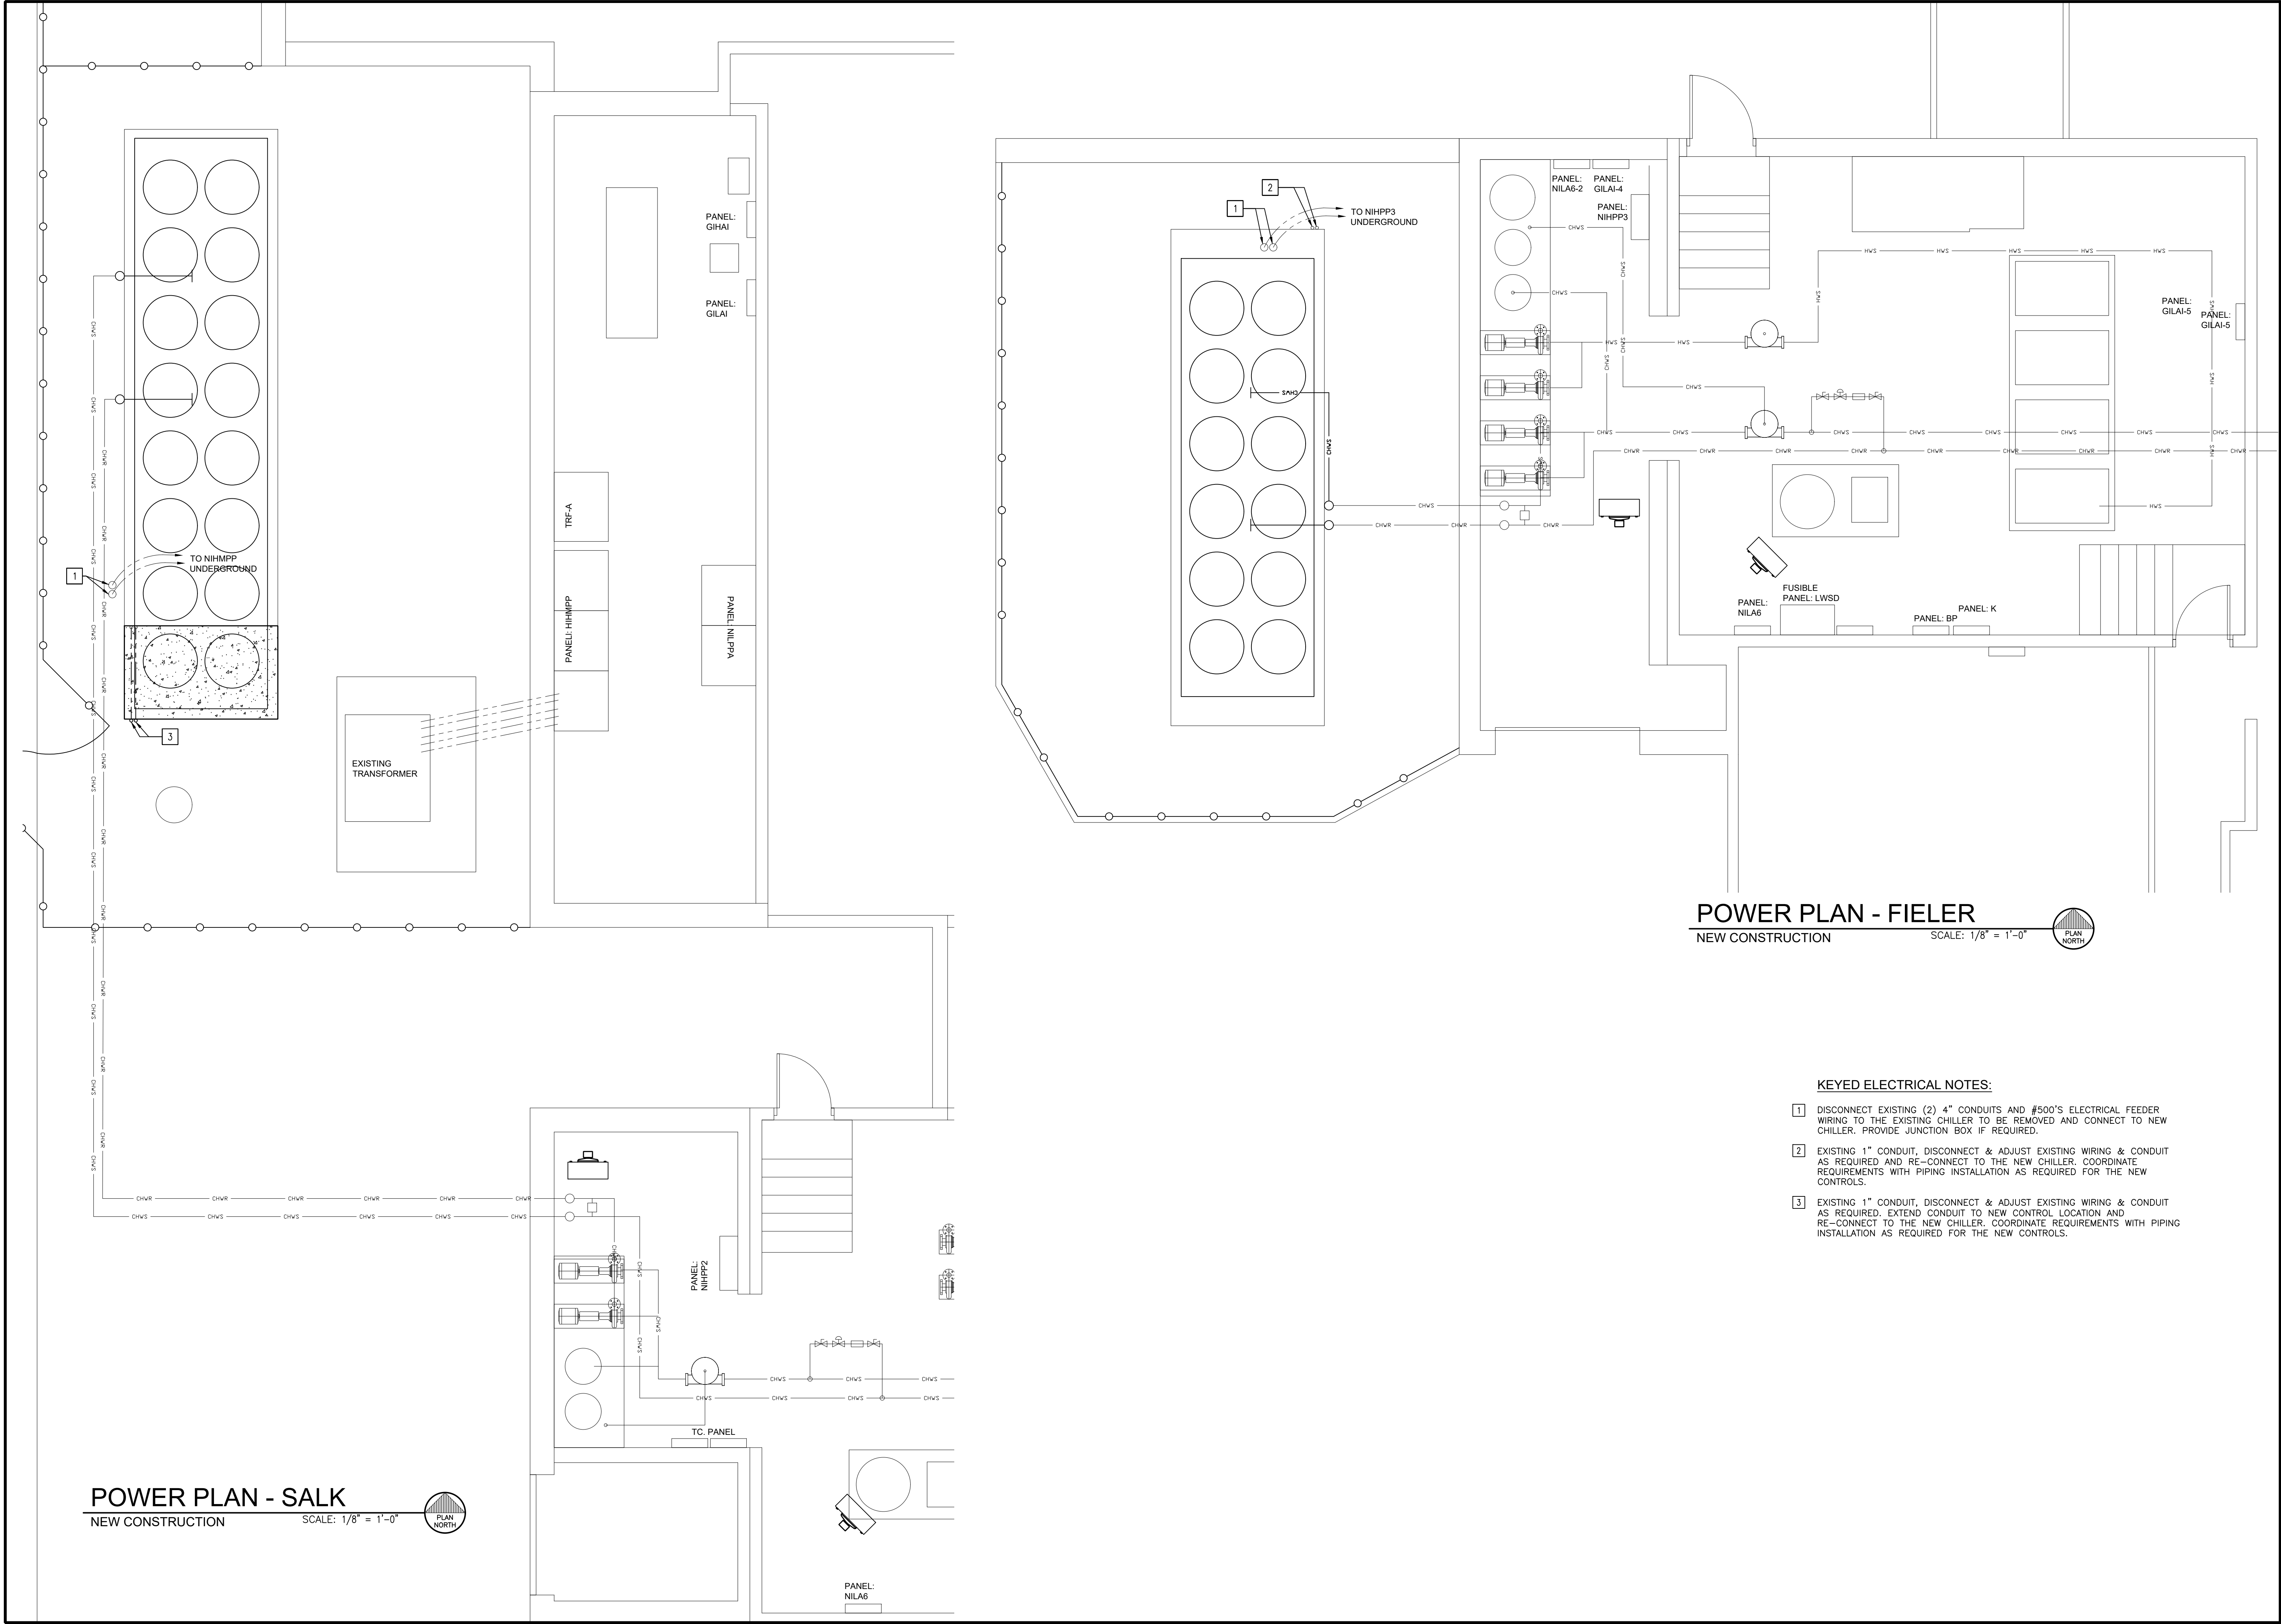


POWER PLAN - FIELER
NEW CONSTRUCTION
SCALE: 1/8" = 1'-0"
PLAN NORTH

KEYED ELECTRICAL NOTES:

- 1 DISCONNECT EXISTING (2) 4" CONDUITS AND #500'S ELECTRICAL FEEDER WIRING TO THE EXISTING CHILLER TO BE REMOVED AND CONNECT TO NEW CHILLER. PROVIDE JUNCTION BOX IF REQUIRED.
- 2 EXISTING 1" CONDUIT, DISCONNECT & ADJUST EXISTING WIRING & CONDUIT AS REQUIRED AND RE-CONNECT TO THE NEW CHILLER. COORDINATE REQUIREMENTS WITH PIPING INSTALLATION AS REQUIRED FOR THE NEW CONTROLS.
- 3 EXISTING 1" CONDUIT, DISCONNECT & ADJUST EXISTING WIRING & CONDUIT AS REQUIRED. EXTEND CONDUIT TO NEW CONTROL LOCATION AND RE-CONNECT TO THE NEW CHILLER. COORDINATE REQUIREMENTS WITH PIPING INSTALLATION AS REQUIRED FOR THE NEW CONTROLS.

POWER PLAN - SALK
NEW CONSTRUCTION
SCALE: 1/8" = 1'-0"
PLAN NORTH

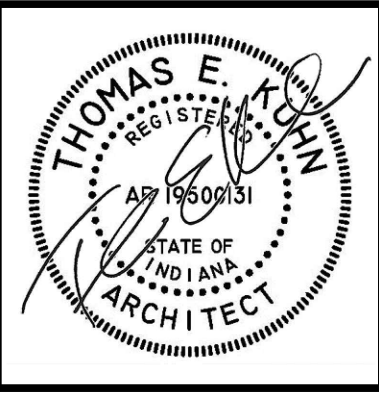

DATE
11/05/2024

CHILLER REPLACEMENT AT
SALK AND FIELER ELEMENTARY SCHOOL
FOR MERRILLVILLE COMMUNITY SCHOOL
6701 DELAWARE STREET
MERRILLVILLE, INDIANA 46410

CSK ARCHITECTS, P.C.
6919 W. LINCOLN HIGHWAY
219-322-5950
CROWN POINT, IN 46307
www.cskarchitects.com

24012

SHEET
2 OF 2