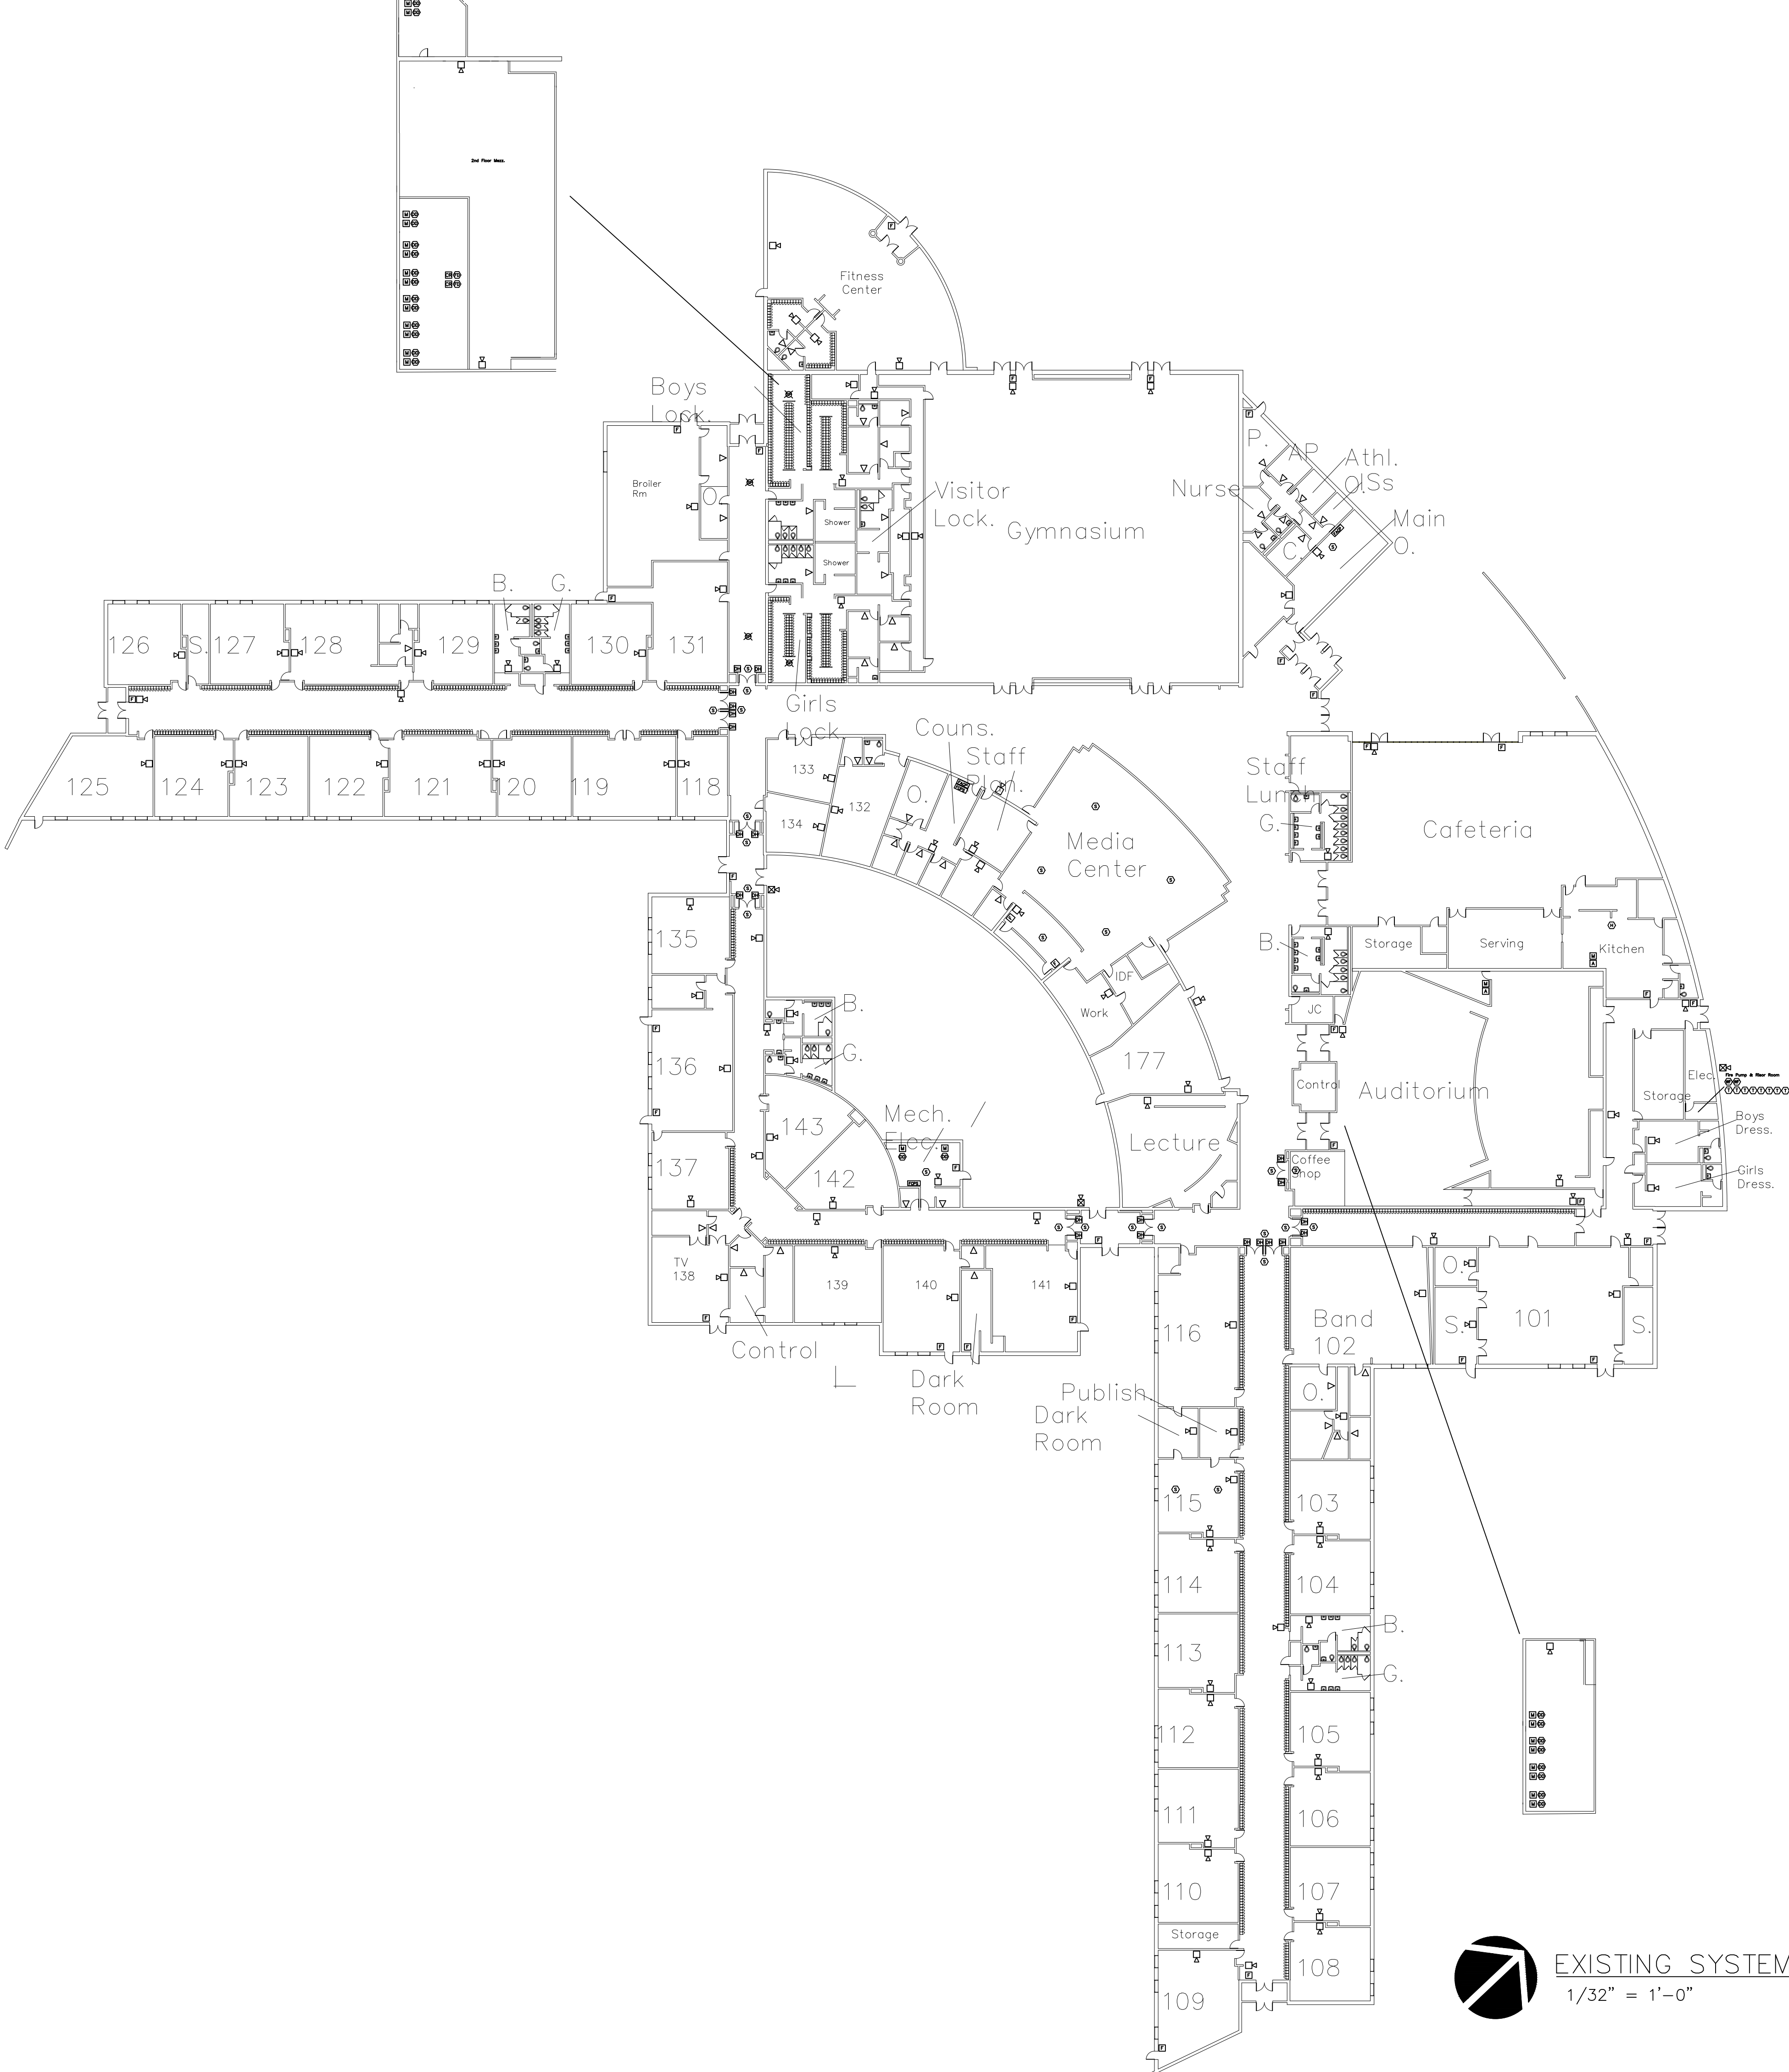


EXISTING SYSTEMS PLAN  
1/32" = 1'-0"

DRAWN BY:  
CHECKED BY:  
PROJECT NUMBER 25.005  
DATE 2025.02.12  
SCALE 1/32" = 1'-0"  
SHEET NUMBER

A 1.0

Project NORTH BRANCH HIGH SCHOOL FIRE ALARM PLAN  
Drawing EXISTING SYSTEM PLAN

| REVISIONS |             |
|-----------|-------------|
|           |             |
|           |             |
|           |             |
|           |             |
|           |             |
|           |             |
| Date      | Description |



ARCHITECT  
SEDGEWICK + FERWEDA ARCHITECTS  
410 East Court Street Flint, MI 48503  
TEL: 810-238-9647 | FAX: 810-238-4900  
www.sfarch.us  
Good clients + Good design + Great architecture

SEAL OF ARCHITECT