

LIVONIA PUBLIC SCHOOLS

STEVENSON HIGH SCHOOL
POOL FILTRATION PROJECT

LIVONIA, MICHIGAN

PROJECT NO. 2024-081

02/19/2025

BIDS



FRENCH

LIST OF DRAWINGS

ARCHITECTURAL

A0.00 ARCHITECTURAL REFERENCE SHEET
A0.02 CODE PLAN

POOL

AQ0.0 POOL REFERENCE PLAN
AQ0.0.1 POOL MECHANICAL ROOM DEMOLITION PLANS
AQ0.0.2 POOL MECHANICAL ROOM RENOVATION PLANS
AQ0.0.3 POOL MECHANICAL ROOM EXISTING CONDITIONS
AQ0.0.4 POOL MECHANICAL ROOM EXISTING CONDITIONS
AQ1.0 POOL MECHANICAL ROOM PLANS
AQ1.1 POOL MECHANICAL DETAILS
AQ1.2 POOL MECHANICAL DETAILS
AQ1.3 POOL MECHANICAL DETAILS
AQ2.0 POOL SYSTEMS DETAILS



MECHANICAL

M0.00 MECHANICAL GENERAL INFORMATION
PD2.10K PLUMBING LOWER LEVEL DEMOLITION PLAN - UNIT K
P2.10K PLUMBING LOWER LEVEL NEW WORK PLAN - UNIT K

ELECTRICAL

E0.00 ELECTRICAL GENERAL INFORMATION
EPD2.10K ELECTRICAL POWER LOWER LEVEL DEMOLITION PLAN - UNIT K
EP2.10K ELECTRICAL POWER LOWER LEVEL NEW WORK PLAN - UNIT K
EP2.11K ELECTRICAL POWER FIRST FLOOR NEW WORK PLAN - UNIT K
EP4.11K ENLARGED ELECTRICAL POWER PLANS - POOL MECHANICAL ROOM
E5.00 ELECTRICAL DETAILS AND PANEL SCHEDULES
E7.00 ELECTRICAL ONE-LINE DIAGRAMS

REFERENCE LOCATION MAP

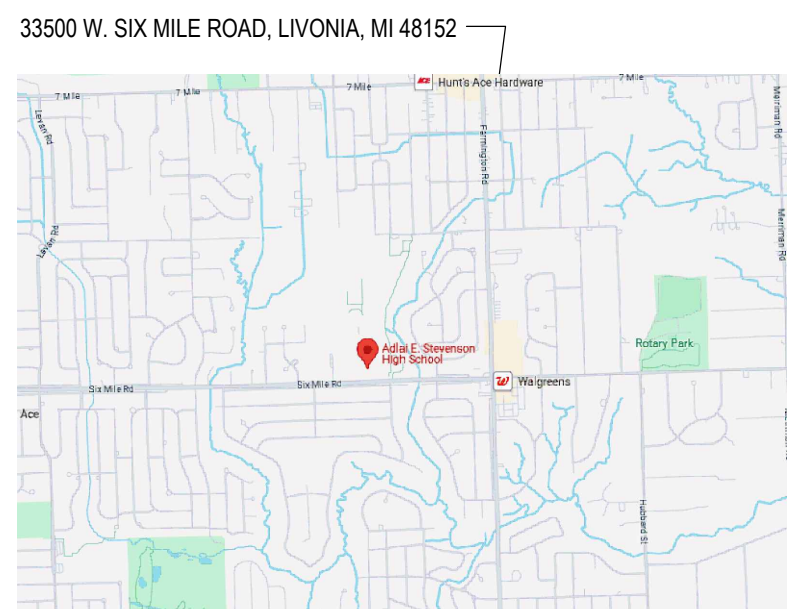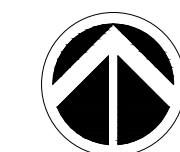

	SOIL
	ASPHALT AGGREGATE
	GRANULAR FILL
	STONE/GRAVEL
	CONCRETE
	CONCRETE MASONRY UNIT
	BRICK
	GLAZED HOLLOW CMU
	STRUCTURAL GLAZED TILE
	LIMESTONE
	MARBLE
	FINISH WOOD
	COMPOSITION/PLYWOOD
	CONTINUOUS WOOD BLOCKING
	BLOCKING OR SHIMS
	BATT INSULATION
	RIGID INSULATION
	PREMOLDED EXPANSION JOINT/ COMPRESSIBLE FILLER STRIP
	PLASTER OR GYPSUM BOARD
	CERAMIC OR QUARRY TILE
	TERRAZZO
	ACOUSTICAL PANEL OR ACOUSTICAL TILE
	EXISTING MATERIAL (IN SECTION)
	EXISTING MATERIAL (IN PLAN)
	DEMOLITION - TO BE REMOVED

C	AIR CONDITIONING	L	LENGTH
ACOUST	ACOUSTICAL	LAM	LAMINATE(D)
ACT	ACOUSTICAL CEILING TILE	LAV	LAVATORY
ADA	AMERICANS WITH DISABILITIES ACT	LB#	POUND
ADJ	ADJUSTABLE	LG	LIGHT GAUGE FRAMING
AFF	ABOVE FINISHED FLOOR	LIN	LINOLEUM
AGG	AGGREGATE	LKR	LOCKER
ALT	ALTERNATE	LLH	LONG LEG HORIZONTAL
ALUM/ALUM	ALUMINUM	LLV	LONG LEG VERTICAL
ANOD	ANODIZED	LMC	LOW METAL CEILING
APC	ARCHITECTURAL PRECAST LINTEL	LOC	LOCK (C)
APPROX	APPROXIMATE	LP	LINEAR PANEL
ARCH	ARCHITECT(URAL)		
ASPH	ASPHALT	MANUF	MANUFACTURER
AV	AUDIO/VISUAL	MAR	MARBLE THRESHOLD
L	ANGLE	MB	MARKER BOARD
		MAS	MASONRY
B CMU	BURNISHED CMU	MAT	MATERIAL/MAT
BIT	BITUMINOUS	MAU	MAKE UP AIR UNIT
BD	BOARD	MAZ	MAXIMUM
BF	BARRIER FREE	MECH	MECHANICAL
BLDG	BUILDING	MEZZ	MEZZANINE
BLK	BLOCK	MIN	MINIMUM/MINUTE
BLKG	BLOCKING	MISC	MISCELLANEOUS
BM	BENCH MARK/BEAM	ML	MASONRY LINTEL
BOT	BOTTOM	MP	METAL PANEL
BRG	BEARING	MWP	METAL WALL PANEL
BUR	BUILT-UP ROOF	MO	MASONRY OPENING
		MT/MTL	METAL
CAB	CABINET	MSF	METAL STUD FRAMING
CUH	CABINET UNIT HEATER	MT	METAL THRESHOLD
CB	CHALKBOARD/CATCH BASIN		
CEM	CEMENT	NIC	NOT IN CONTRACT
CF	CERAMIC	NO#	NUMBER
CFM	CUBIC FEET PER MINUTE	NOM	NOMINAL
CJ	CONTROL JOINT	NSF	NON-SLIP FINISH
CL	CENTERLINE	NTS	NOT TO SCALE
CLG	CEILING		
CLR	CLEAR	OC	ON CENTER
CMU	CONCRETE MASONRY UNIT	OD	OUTSIDE DIAMETER
COL	COLUMN	OH	OVERHEAD DOOR
COMP	COMPACTED	OPNG	OPENING
CONC	CONCRETE	OPP	OPPOSITE
CONST	CONSTRUCTION	OS	OVERFLOW SUMP
CONT	CONTINUOUS/CONTINUE		
CONTR	CONTRACTOR	PART	PARTICLE
CORR	CORRUGATED	PARTN	MOVABLE PARTITION
CPL	CEMENT PLASTER	PC	PRECAST CONCRETE
CPT	CARPET	PL	PLATE/PROPERTY LINE
CT	CERAMIC TILE	PLAS	PLASTER
CU	CONDENSING UNIT	PLAM	PLASTIC LAMINATE
CUSP	CLUSIDOR	PLYW/D	PLYWOOD
CWF	CURTAINWALL FRAMING	PREFAB	PREFABRICATED
		PREFIN	PREFINISHED
D	DEPTH/DEEP	PSF	POUNDS PER SQUARE FOOT
D	DEGREE	PSI	POUNDS PER SQUARE INCH
DC	DISPLAY CASE	PTD	PAINTED
DEMO	DEMOLISH/DEMOLITION	PVC	POLYVINYL CHLORIDE
DTL	DETAIL		
DF	DRINKING FOUNTAIN	QT	QUARRY TILE
DIA/Ø	DIAMETER		
DM	DIMENSION	R	RISER/RADIUM
DIV	DIVISION	RB	RESILIENT WALL BASE/RUBBER BASE
DS	DOWNSPOUT	RBF	RUBBER FLOORING
DWG	DRAWING	RC	RAIN CONDUCTOR
		RES	RESILIENT
EA	EACH	RS	ROOF SUMP
EJ	EXPANSION JOINT	REF	REFERENCE
EL	ELEVATION	REFR	REFRIGERATOR
ELEC	ELECTRICAL	REINF	REINFORCING
ELEV	ELEVATOR	REQ'D	REQUIRED
EQ	EQUAL	REV	REVISION(S)
EQUIP	EQUIPMENT	RF	ROOF EXHAUST FAN
EIFS	EXTERIOR INSULATION FINISH	RM	REMOVABLE MULLION/ROOM
EW	ELECTRIC WATER COOLER	RO	ROUGH OPENING
EXH	EXHAUST	R/O	RIGHT OF WAY
EX/EXIST	EXISTING	RTU	ROOF TOP UNIT
EXP	EXPANSION	RV	ROOF VENT
EXT	EXTERIOR		
		S	SINK
FD	FLOOR DRAIN	SAC	SINK APPLIED ACOUSTICAL COATING
FEC	FIRE EXTINGUISHER CABINET	SCHED	SCHEDULE
FF	FORCED FLOW CABINET HEATER	SEAL	CONCRETE SEALER
FHC	FIRE HOSE CABINET	SEC	SECTION
FIN	FINISH	SFF	STOREFRONT FRAMING
FIN FL	FINISH FLOOR	SHT	SHEET
FLR	FLOOR	SIM	SIMILAR
FOUND	FOUNDATION	SPEC(S)	SPECIFICATIONS
FT/	FEET	SP CMU	SPLIT FACE CMU
FTG	FOOTING	SPI	SPORTS IMPACT FLOORING
FRP	FIBERGLASS REINFORCED POLYESTER	SPKR	SPEAKER
		SQ	SQUARE
GA	GAUGE	SS	SERVICE SINK/STAINLESS STEEL
GALV	GALVANIZE(D)	SSM	SOLID SURFACE MATERIAL
GB	GRAB BARS	STD	STANDARD
GHT	GLAZED HOLLOW TILE	STL	STEEL
GL	GLASS	STRUCT	STRUCTURAL
GL CMU	GLAZED CMU	SUSP	SUSPENDED
GLZD	GLAZED	SVT	SOLID VINYL TILE
GYP	GYPSUM	SV	SHEET VINYL
		T	TREAD
H/HGT	HEIGHT	T&B	TOP AND BOTTOM
HB	HOSE BIB	TB	TACK BOARD
HLM	HOLLOW METAL	TC	TOP OF CURB
HORIZ	HORIZONTAL	TEMP	TEMPERED
HP	HIGH POINT	TER	TERRAZZO
HR	HOUR	TOC	TOP OF CONCRETE
HVAC	HEATING/VENTILATING/AIR CONDITIONING	TOF	TOP OF FOOTING
		TOM	TOP OF MASONRY
		TOS	TOP OF STEEL
ID	INSIDE DIAMETER	TS	TUBE STEEL
IN/	INCH	TV	TELEVISION
INCL	INCLUDE(D),(ING)	TYP	TYPICAL
INSUL	INSULATION/INSULATE(D)		
INT	INTERIOR	UNO	UNLESS NOTED OTHERWISE
		UV	UNIT VENTILATOR
KIT	KITCHEN		
		VCT	VINYL COMPOSITION TILE
JST	JOIST	VCG	VINYL COVERED GYPSUM BOARD
JT	JOINT	VERT	VERTICAL
		VIF	VERIFY IN FIELD
		VUV	VERTICAL UNIT VENTILATOR
		W/	WITH
		WO	WITHOUT
		WC	WATER CLOSET

DETAIL IDENTIFICATION

DETAIL TITLE

SCALE: 1" = 1'-0"

FOR CROSS-REFERENCING: SHEETS WHERE DETAIL IS CUT

DRAWING SYMBOL

DETAIL IDENTIFICATION

DETAIL LOCATOR

INTERIOR ELEVATION IDENTIFICATION

EXTERIOR ELEVATION IDENTIFICATION

SHEET WHERE ELEVATION IS DRAWN

ELEVATION SYMBOL

BUILDING SECTION IDENTIFICATION

BUILDING SECTION LOCATOR

PLAN OR DETAIL IDENTIFICATION

PLAN OR DETAIL BLOW-UP

EXISTING

NEW

COLUMN GRID

NAME

A101

ROOM

FLOOR

BUILDING/UNIT

ROOM NAME AND NUMBER

BUILDING/UNIT

FLOOR

ROOM

A101A

DOOR IF MORE THAN ONE DOOR PER ROOM

NEW DOOR

EXISTING DOOR

DOOR NUMBER AND SYMBOLS

X-X12

2

2

PARTITION TYPE

EQUIPMENT TYPE

CONSTRUCTION / DEMO NOTE

ADDENDUM (ADD), CONSTRUCTION CHANGE DIRECTIVE (CCD), OR ARCHITECT'S SUPPLEMENTAL INSTRUCTIONS (ASI)

ITEM NUMBER

AREA OF CURRENT CHANGE

AREA OF PREVIOUS CHANGE

MISCELLANEOUS SYMBOLS

CONVENIENCE CONTROLS AND OUTLETS

ELEVATORS

SHOWER UNIT

BARRIER FREE URINAL

BARRIER FREE WATER CLOSET

STALL LAYOUT

BARRIER FREE LAVATORIES AND MIRRORS

RAMP HANDRAIL

STAIR HANDRAIL

FIRE EXTINGUISHER EQUIPMENT

DRINKING FOUNTAIN/ELECTRIC WATER COOLER

TOILET ROOM ACCESSORIES

TOILET ROOM SIGNAGE

TACK BOARDS AND MARKER BOARDS

INTERACTIVE PANEL MOUNTING

NOTE: HEIGHT ABOVE FLOOR TO BASELINE OF CHARACTER TO COMPLY WITH ICC/ANSI A117.1-2009 TABLE 703.2.4

ISSUE DATE	ISSUED FOR
02/19/2025	BIDS
DRAWN	AMN
CHECKED	AMN
APPROVED	DCJ



SHEET

PROJECT NUMBER

2024-081

SHEET NUMBER

Cleveland Elementary School Renovation

- 1) Design Codes
 - a)2015 Michigan Rehabilitation Code (Existing Building)
 - b)2018 School Fire Safety Rules
 - c)NFPA 101 Life Safety Code 2012 edition
 - d)2021 Michigan Plumbing Code
 - e)2021 Michigan Mechanical Code
 - f) 2015 Michigan Uniform Energy Code
 - g)2023 Michigan Electrical Code Rules, Part 8
 - h)2020 National Electrical Code (NFPA 70)
 - i) 2009 ICC A117.1 Accessible and Usable Buildings & Facilities
- 2) Design Professional in Responsible Charge (106.6)
 - a)A representative of French Associates will be the Design Professional in Responsible Charge.
- 3) Existing Building information
 - a) story, 1st floor = 316,492 square feet.
Mezzanine floor = 15,200 square feet.
Total = 333,692 square feet.
 - b)the building is not sprinkled, except for the performance arts center.
 - c)Type of Construction is IB (II-000 from School Fire Safety Rules)
 - d)Use Group is Occupancy E (Education)
- 4) Compliance Method (Chapter 3)
 - a)Work Area Compliance Method (301.1.2). The work shall comply with the applicable requirements of Chapters 8 through 11.
- 5) Classification of Work (Chapter 5)
 - a)As defined by the Michigan Rehabilitation Code, the work includes Level 1 Alterations and Level 2 Alterations. The Work Area does not exceeds 50% of the Building Area.
 - b)There is no change of occupancy.
 - c)There is no addition.
 - d)Under the School Fire Safety Rules, the scope of work in the Level 1 Alterations is the replacement of existing finishes and systems. As a result, the Level 1 Alteration areas do NOT qualify as remodeling.
 - e)The Level 2 Alteration areas are being remodeled as defined by the School Fire Safety Rules. The Level 2 Alteration areas is less than 50% of the building area so we are NOT required to bring the whole building into compliance.
- 6) Chapter 7- Alterations- Level 1
 - a)Section 702.1- New interior finishes will comply with Chapter 8 of the Michigan Building Code.
i) From Table 903.9- Corridors are Class B finishes, Rooms are Class C finishes
ii) Interior finishes shall comply with Section 904 of MEC.
- 7) NFPA 101 Life Safety Code, Chapter 11, Existing Educational Occupancies.
 - a)The spaces being remodeled (Level 2 Alterations) are designed to comply with the requirements of Chapter 11, Existing Educational Occupancies.
 - b)11-2.2 through 11-2.5- Existing Means of Egress components comply.
 - c)11-2.6 travel Distance to Exits- Existing exit travel distances are being maintained. In locations where the travel distance to an exit is being changed by the Addition, the rooms have an Exit Travel Distance of less than 200'.
 - d)11-2.8 through 11-2.10- New light fixtures, emergency lighting and exit signs are part of the remodel and will comply.
 - e)11-3.2- The existing Lobby Room is separated from the rest of the building by a 1 hour fire barrier.
 - f)11-3.3- Interior finishes of Corridors are Class B, minimum. All other locations are Class C, minimum.
 - g)The existing fire alarm system is being maintained.
 - h)11-3.6- We are not remodeling the corridors or most classroom spaces, just replacing ceilings, lights and finishes as required in 11-3.6. In locations where we are remodeling, the corridor wall is being maintained as existing.
 - i)11-3.7- The existing building is sub-divided into existing fire areas.

EXISTING BUILDING AREA: FIRST FLOOR 318,492 SF.
MEZZANINE FLOOR = 15,200 SF.
TOTAL = 333,692 SF.

STUDENT POPULATION IS NOT CHANGING

WORK AREA COMPLIANCE METHOD: LEVEL 1 ALTERATIONS


NO CHANGE OF USE

EXISTING BUILDING IS NOT SPRINKLED.

ALTERATION LEVEL 1 DESCRIPTION:

- REPLACEMENT AND UPGRADING OF EXISTING POOL EQUIPMENT SYSTEMS.


ISSUE DATE	ISSUED FOR
02/19/2025	BIDS
DRAWN	AMN
CHECKED	AMN
APPROVED	DCJ


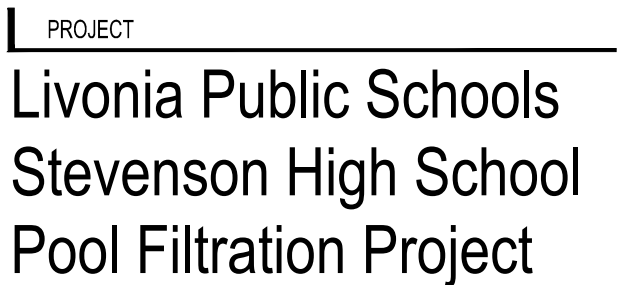


COMPOSITE CODE PLAN

2024-081

A0.02

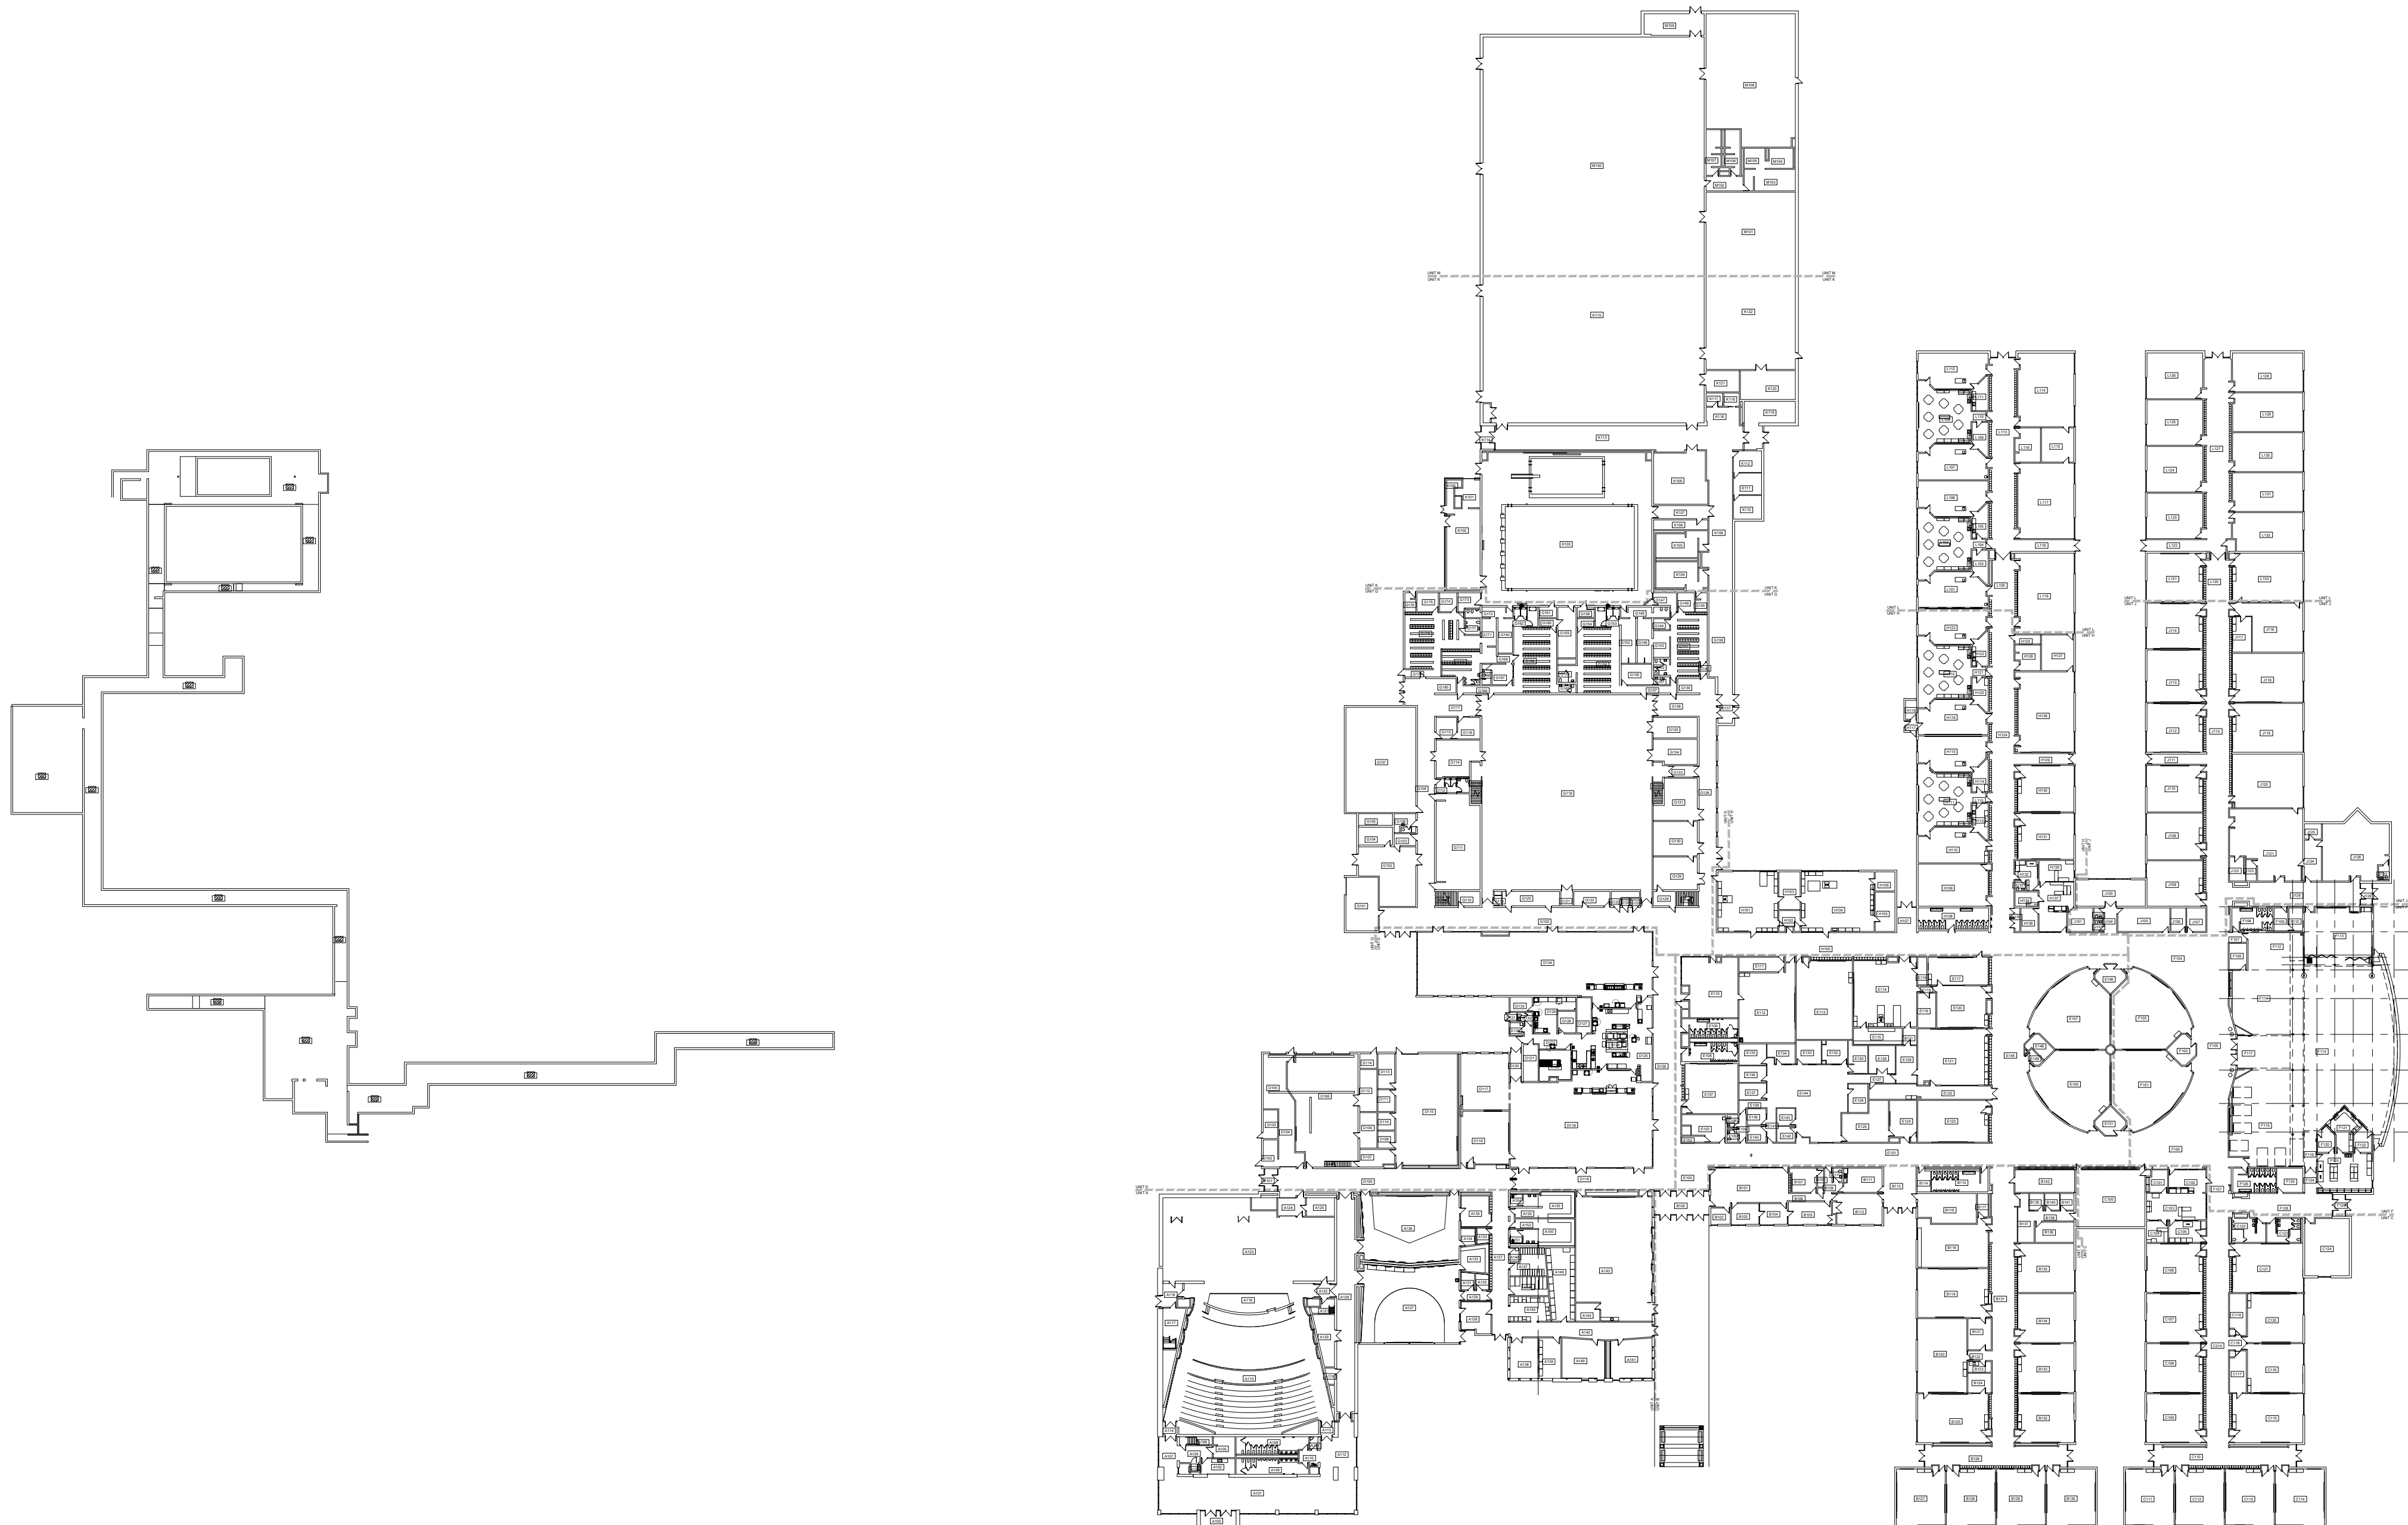

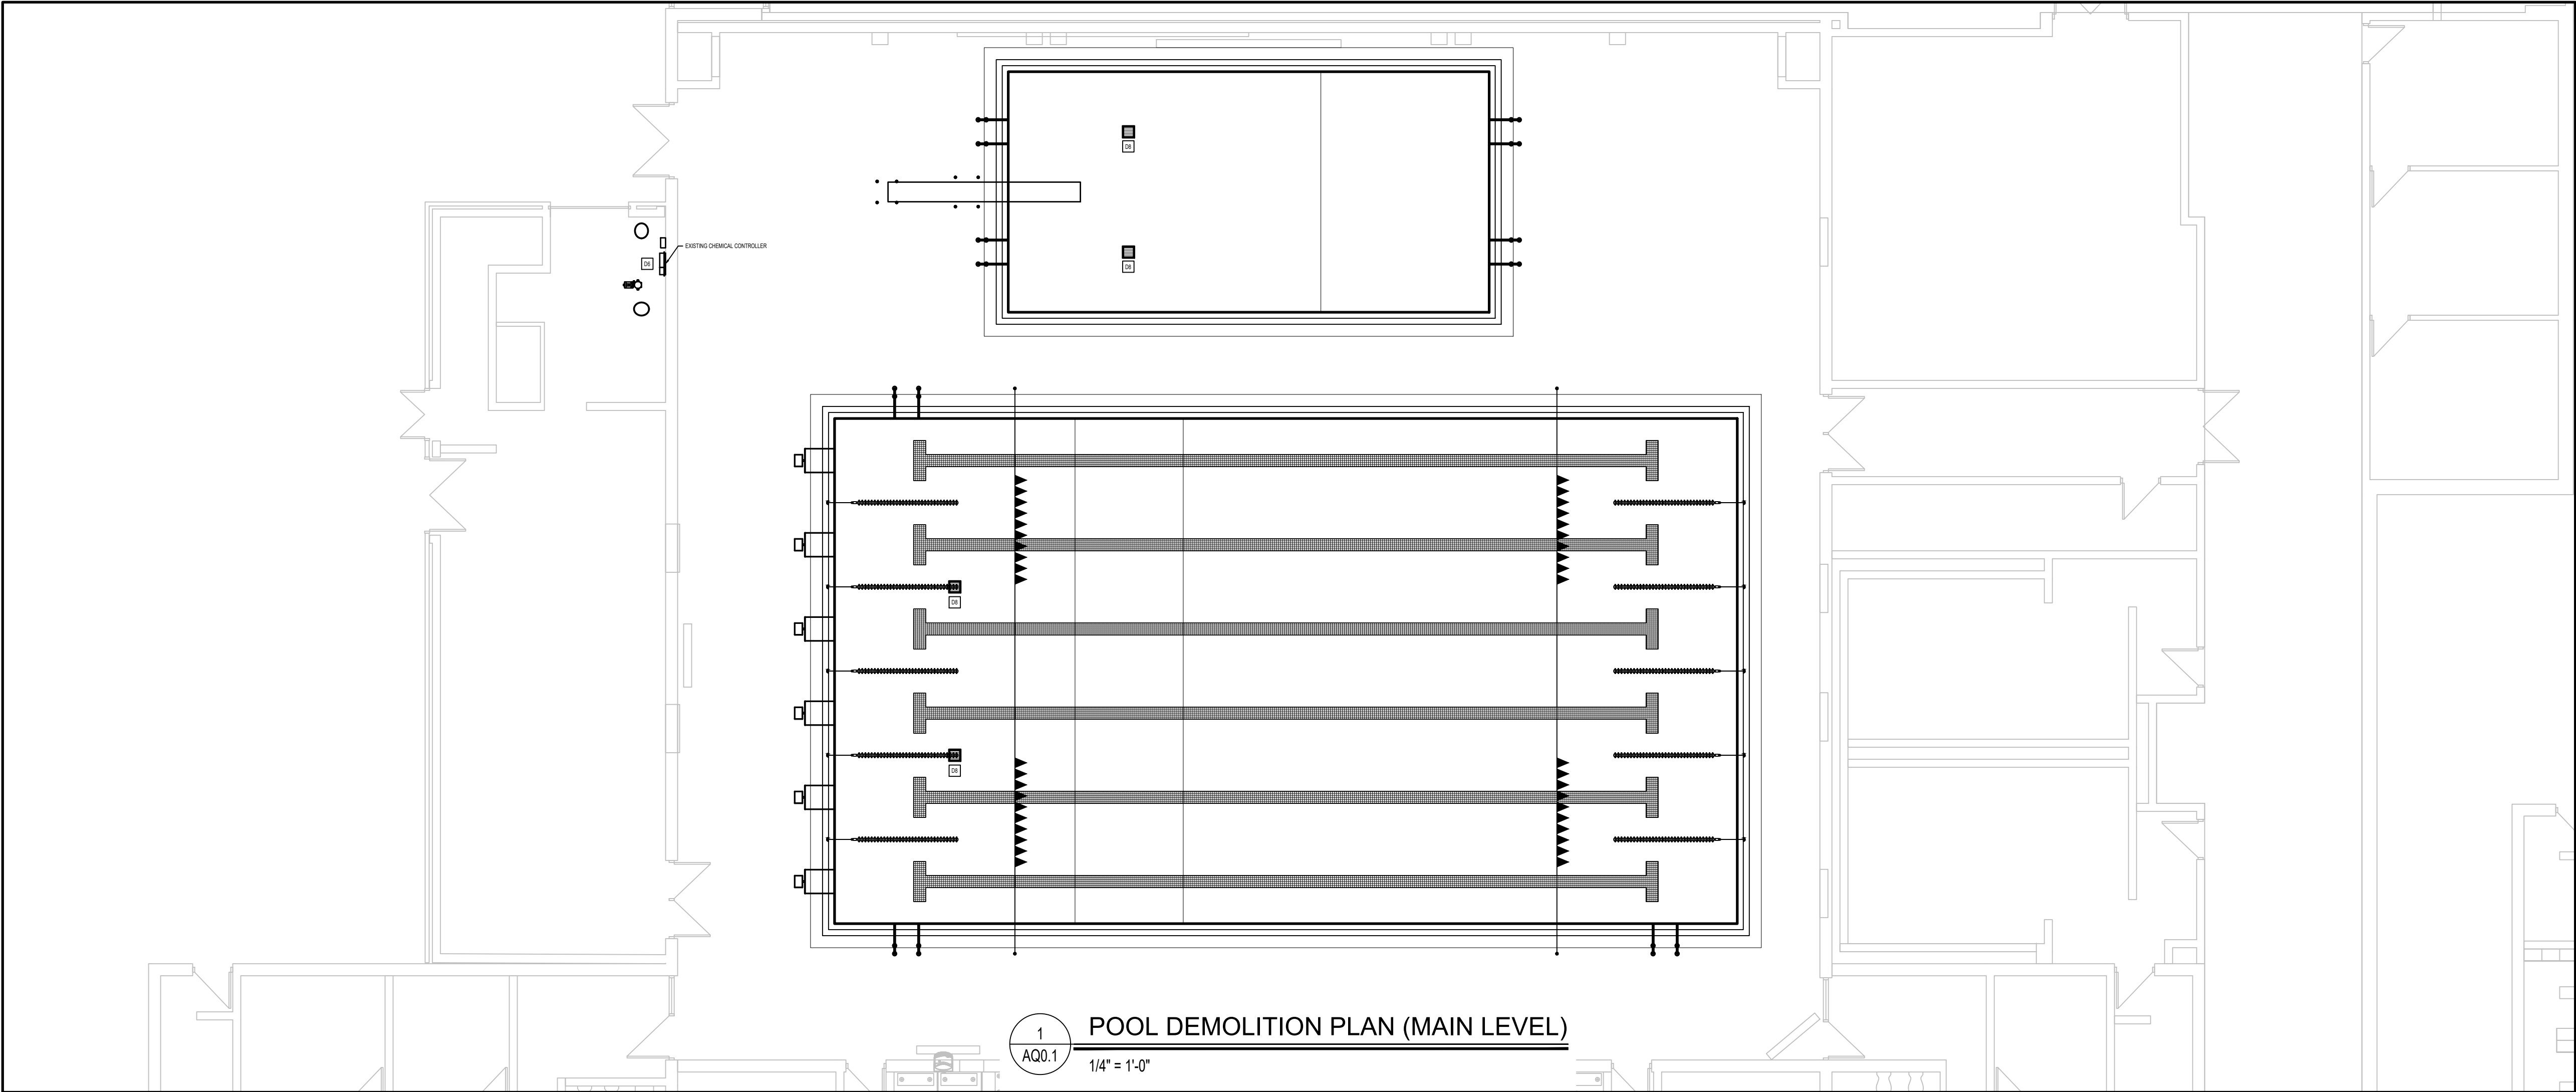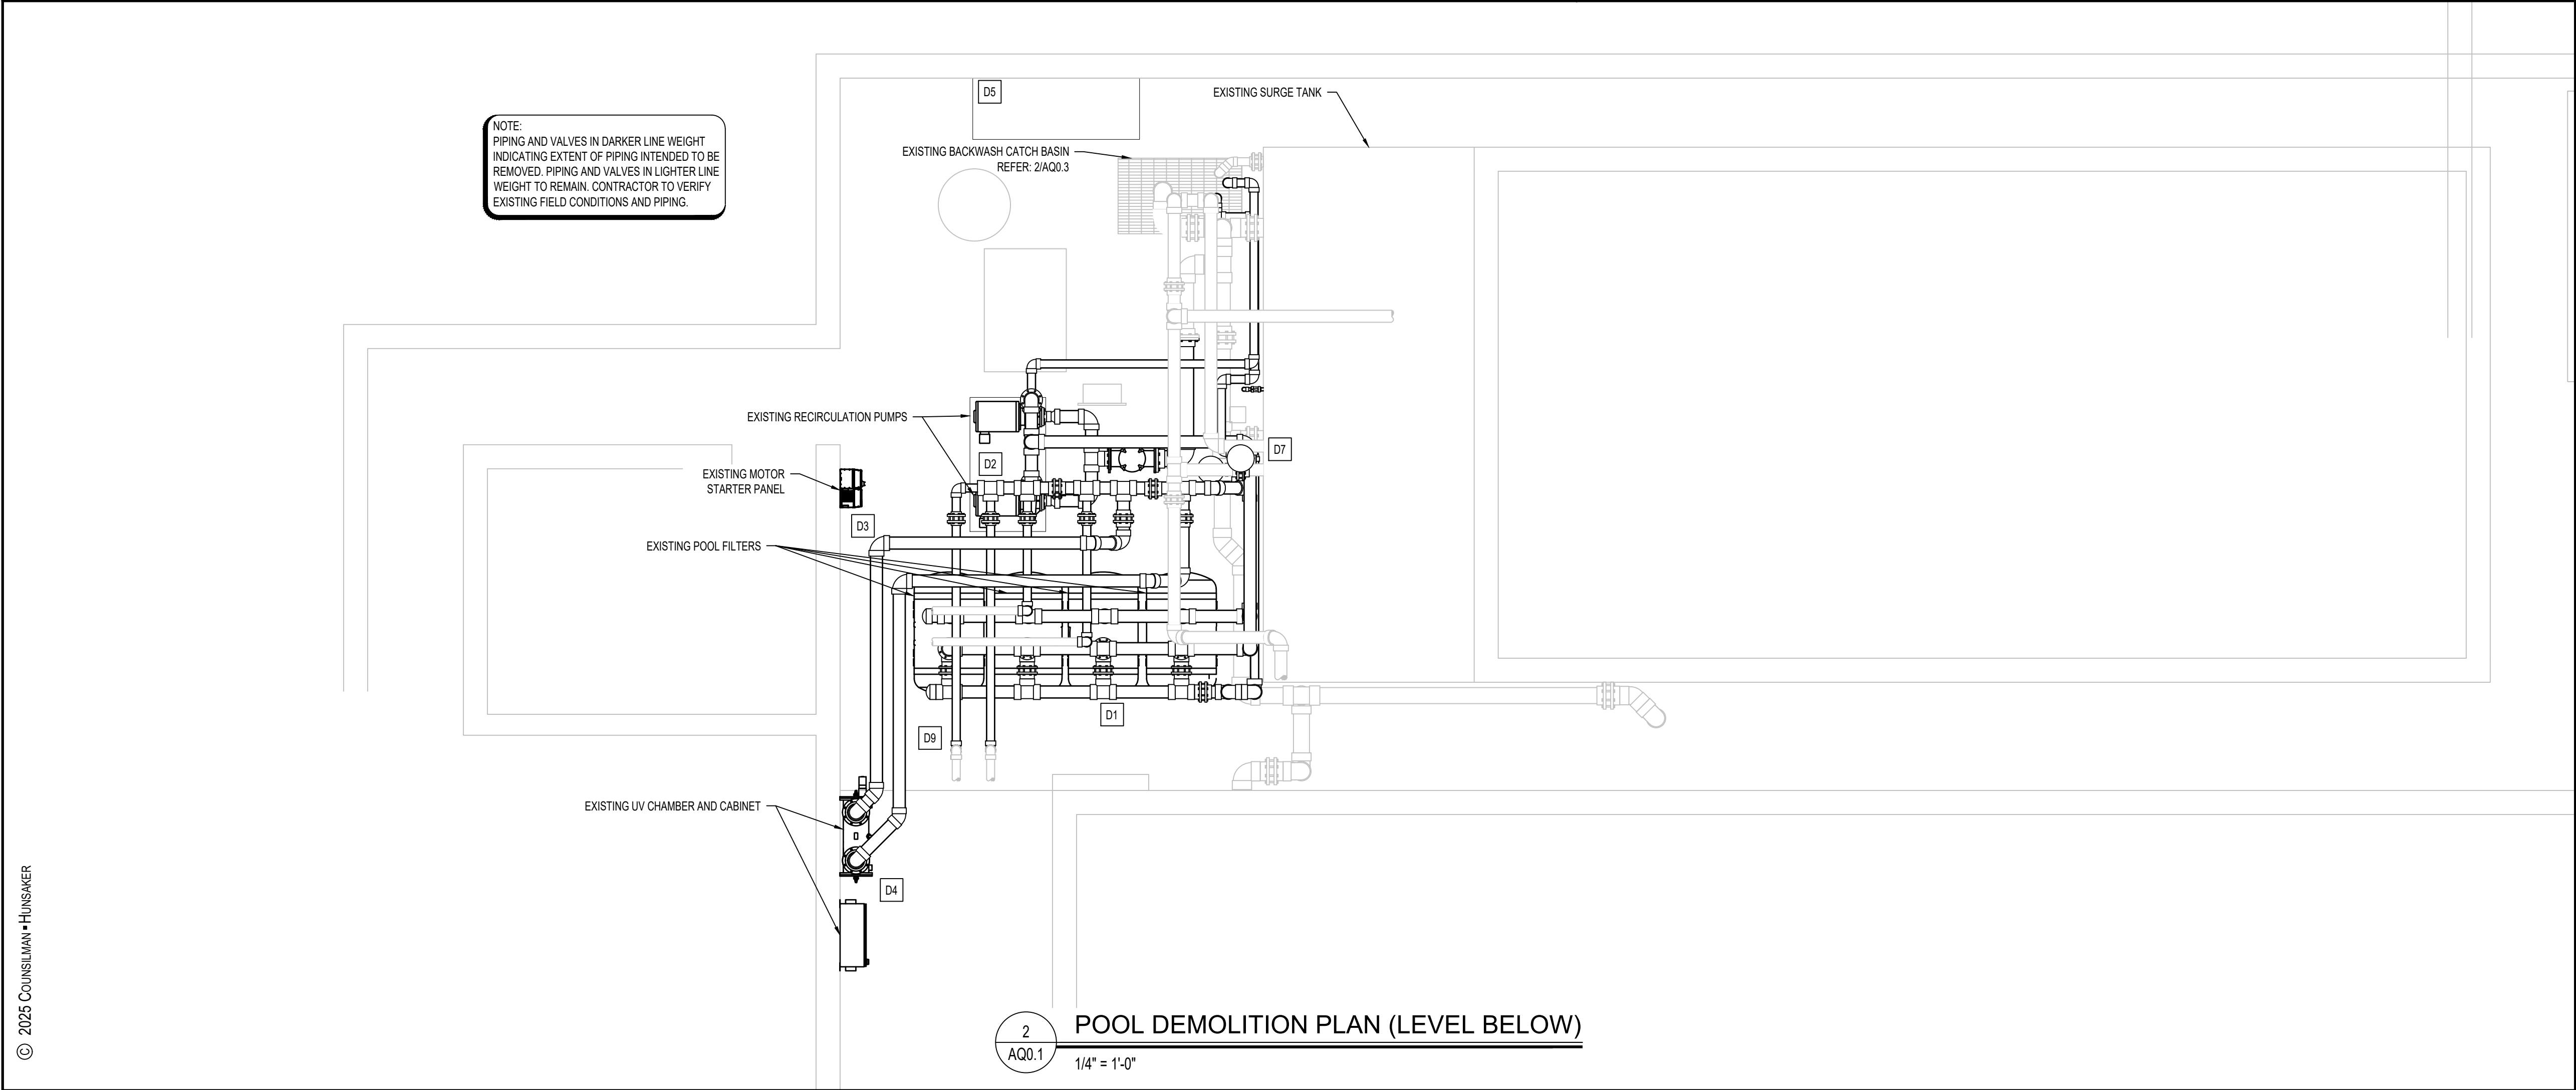

- ### GENERAL POOL DEMOLITION AND RENOVATION NOTES
- COORDINATE ALL DEMOLITION PLANS AND WORK WITH ARCHITECT AND CONSTRUCTION DOCUMENTS PRIOR TO THE START OF DEMOLITION.
 - REVIEW RECORD DOCUMENTS OF EXISTING CONSTRUCTION PROVIDED BY THE OWNER. NEITHER THE OWNER NOR ENGINEER MAKES ANY GUARANTEE THAT THE EXISTING CONDITIONS REFLECT THOSE INDICATED IN THE RECORD DOCUMENTS. CONTRACTOR TO PROVIDE NOTIFICATION OF ANY DISCREPANCIES BETWEEN EXISTING CONDITIONS AND THE CONTRACT DOCUMENTS BEFORE PROCEEDING WITH DEMOLITION.
 - CONTRACTOR TO SURVEY EXISTING CONDITIONS AND CORRELATE WITH REQUIREMENTS INDICATED IN THE CONTRACT DOCUMENTS TO DETERMINE THE EXTENT OF DEMOLITION REQUIRED. CONTRACTOR TO RECORD EXISTING CONDITIONS WITH DETAILED PRECONSTRUCTION PHOTOGRAPHS.
 - UNLESS OTHERWISE INDICATED, DEMOLITION WASTE BECOMES PROPERTY OF THE CONTRACTOR.
 - EXCEPT FOR ITEMS OR MATERIALS INDICATED TO BE RECYCLED, REUSED, SALVAGED, REINSTALLED, OR OTHERWISE INDICATED TO REMAIN OWNERS PROPERTY, REMOVE DEMOLISHED MATERIALS FROM PROJECT SITE AND LEGALLY DISPOSE OF THEM. OWNER HAS THE FIRST RIGHT OF REFUSAL ON ALL DEMOLITION MATERIALS.
 - IF HAZARDOUS MATERIALS ARE ENCOUNTERED, DO NOT DISTURB. IMMEDIATELY NOTIFY THE OWNER AND ENGINEER.
 - INDICATE RECEIPT AND ACCEPTANCE OF ANY HAZARDOUS WASTES BY A LANDFILL FACILITY LICENSED TO ACCEPT SUCH HAZARDOUS WASTES.
 - MAINTAIN EXISTING UTILITIES TO REMAIN IN SERVICE AND PROTECT THEM AGAINST DAMAGE DURING DEMOLITION OPERATIONS. REFER TO OTHER TRADES FOR COORDINATION.
 - ELECTRICIAN MUST VERIFY EXISTING BOND GRID. ALL NEW EMBEDS AND MECHANICAL EQUIPMENT MUST BE BONDED PER NEC ARTICLE 680.
 - PROTECT ALL EXISTING POOL FINISHES, GUTTERS, MAIN DRAINS, AND ANY OTHER POOL RELATED APPURTENANCES DURING CONSTRUCTION.
 - THE CONTRACTOR MUST BE RESPONSIBLE FOR CONTINUOUSLY MONITORING GROUNDWATER LEVELS ON THE SITE DURING ANY AND ALL PERIODS WHEN THE SWIMMING POOL IS NOT FULL OF WATER. PROTECTION OF THE EXISTING POOL STRUCTURE FROM DAMAGE DUE TO HYDROSTATIC PRESSURE IS THE SOLE RESPONSIBILITY OF THE CONTRACTOR.
 - CONTRACTOR TO PROVIDE AND EXECUTE APPROVED DUST CONTROL PLAN.
 - ALL AREAS OF WORK MUST HAVE DOUBLE CONTAINMENT AND DEDICATED EXHAUST INDEPENDENT OF HVAC.
 - CLEAN ADJACENT STRUCTURES AND IMPROVEMENTS OF DUST, DIRT, AND DEBRIS FOLLOWING DEMOLITION OPERATIONS. CONTRACTOR TO RETURN ADJACENT AREAS TO CONDITION EXISTING BEFORE THE START OF DEMOLITION OPERATIONS.

POOL DEMOLITION KEYNOTES	
COORDINATE ALL DEMOLITION PLANS WITH ARCHITECT AND CONSTRUCTION DOCUMENTS PRIOR TO DEMOLITION	
D1	REMOVE EXISTING SAND FILTERS. REFER: 4/AQ0.3
D2	REMOVE EXISTING RECIRCULATION PUMPS AND STRAINER. REFER: 3/AQ0.3
D3	REMOVE EXISTING MOTOR STARTER PANEL. REFER: 5/AQ0.3
D4	REMOVE EXISTING UV CHAMBER AND CABINET. REFER: 6/AQ0.3
D5	REMOVE EXISTING YELLOW GRATING SHELF AGAINST MECHANICAL ROOM WALL. REFER: 6/AQ0.3
D6	REMOVE EXISTING CHEMICAL CONTROLLER. REFER: 2/AQ0.4
D7	REMOVE TWO EXISTING FISHER VALVES. REFER: 9 & 10/AQ0.3
D8	REMOVE THE EXISTING VGB COVERS AT THE FOUR (4) DRAIN SUMPS. REFER: 3 & 4/AQ0.4
D9	REMOVE EXISTING FLOW METER SENSORS REFERENCES: 7/AQ0.3

KEY PLAN	
ISSUE DATE	ISSUED FOR
02/19/2025	BIDS
DRAWN	ZRW
CHECKED	ALJ
APPROVED	CPN

FRENCH

2851 High Meadow Circle | Suite 100
Auburn Hills | MI 48326
248.656.1377

COUNSILMAN+HUNSAKER
AQUATICS FOR LIFE
ph: 314.894.1246 • www.chh2o.com

PROJECT

**Livonia Public Schools
Stevenson High School
Pool Filtration Project**

LIVONIA,
MICHIGAN

SHEET



**POOL
MECHANICAL
ROOM
DEMOLITION
PLANS**

PROJECT NUMBER

2024-081

SHEET NUMBER

AQ0.1

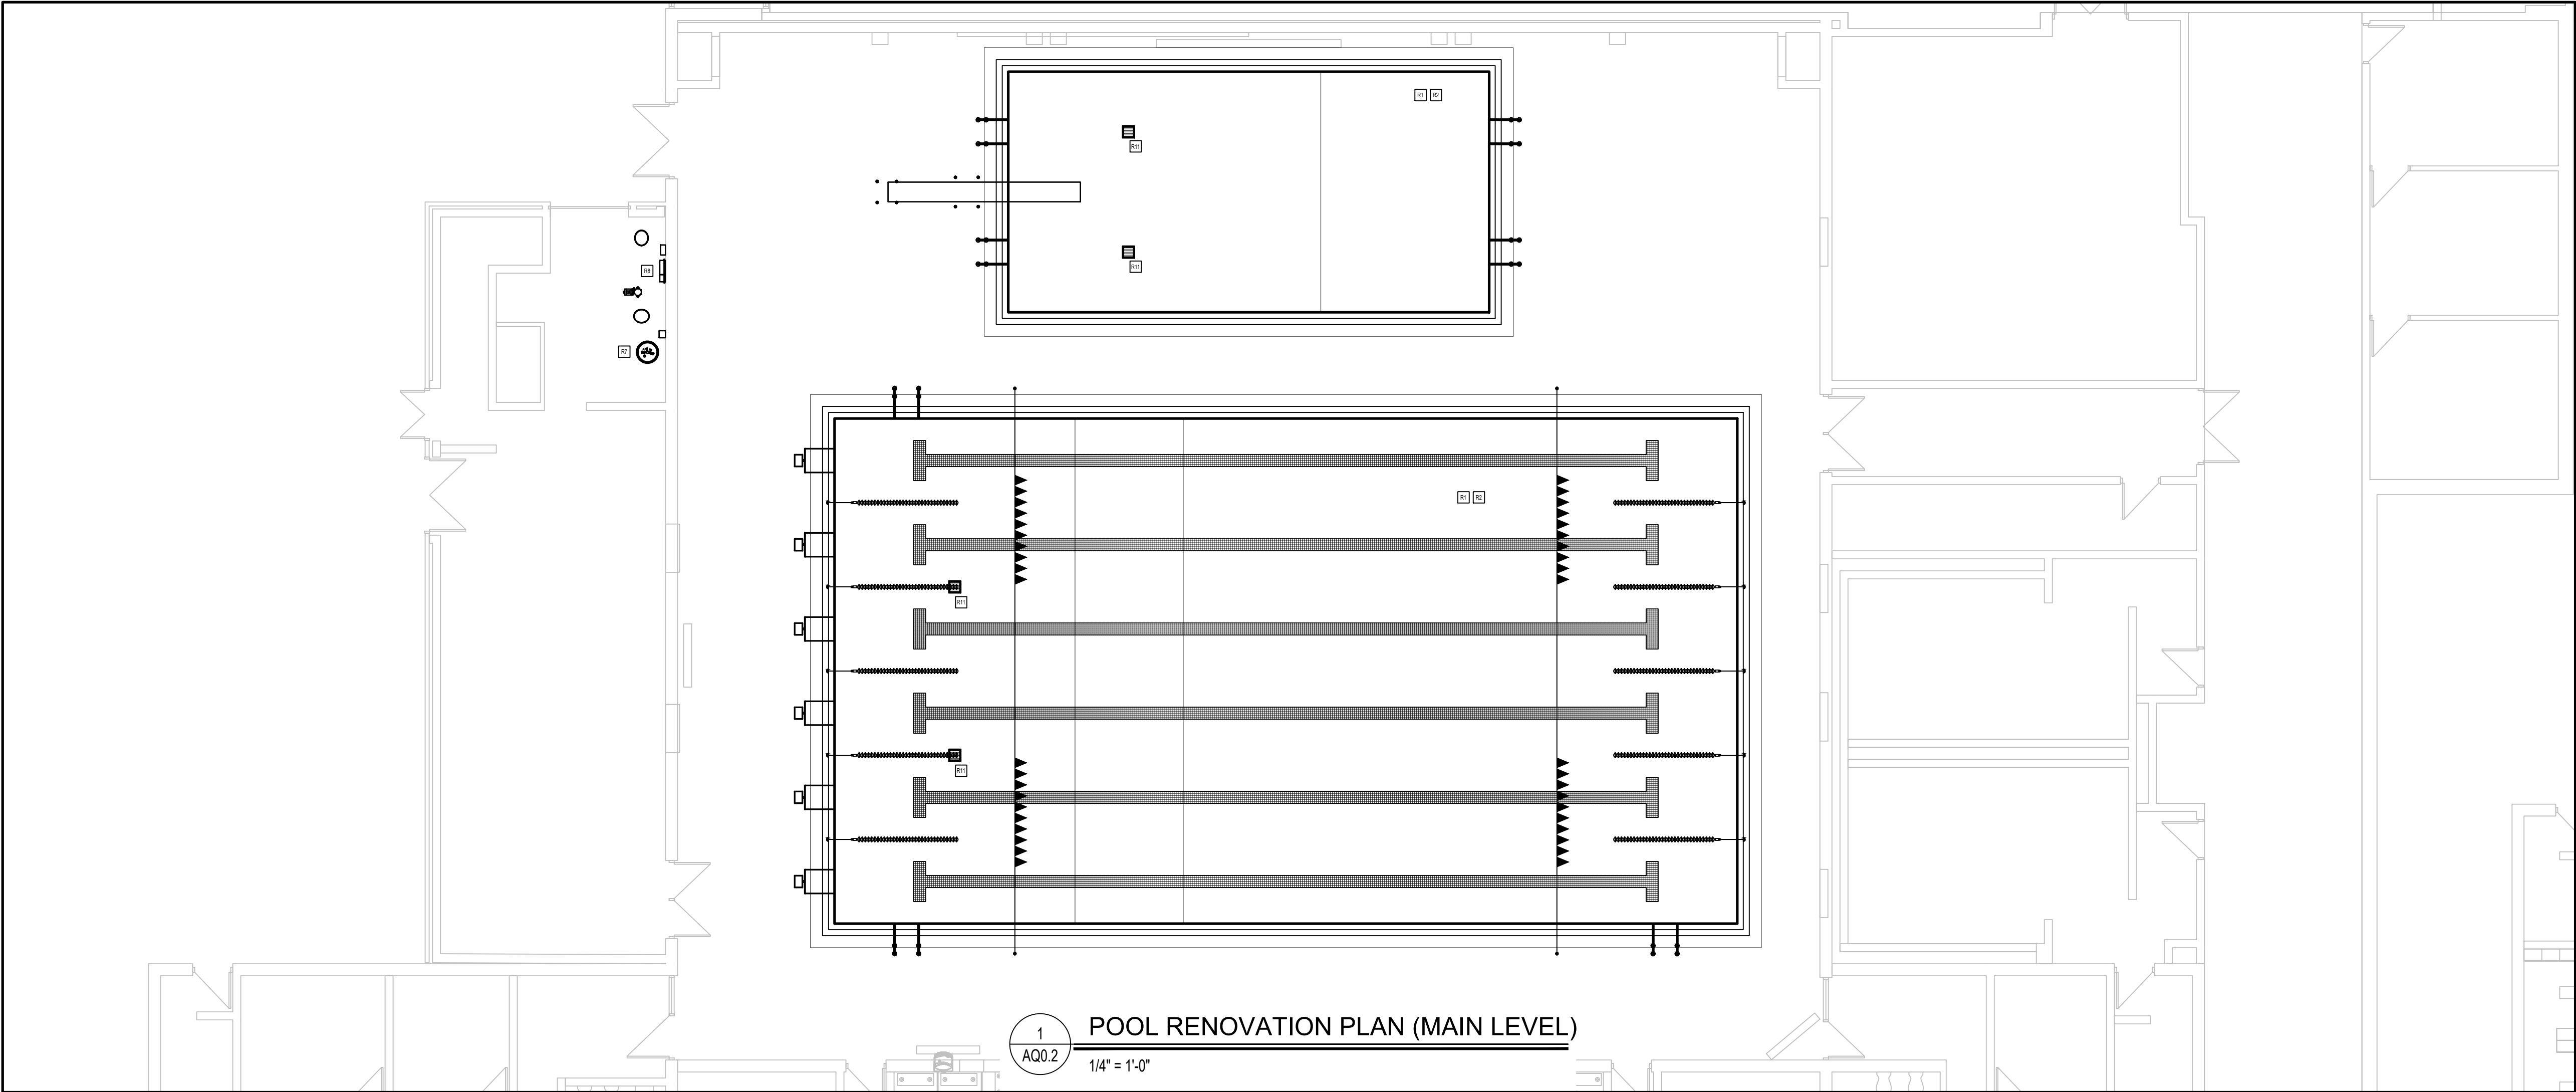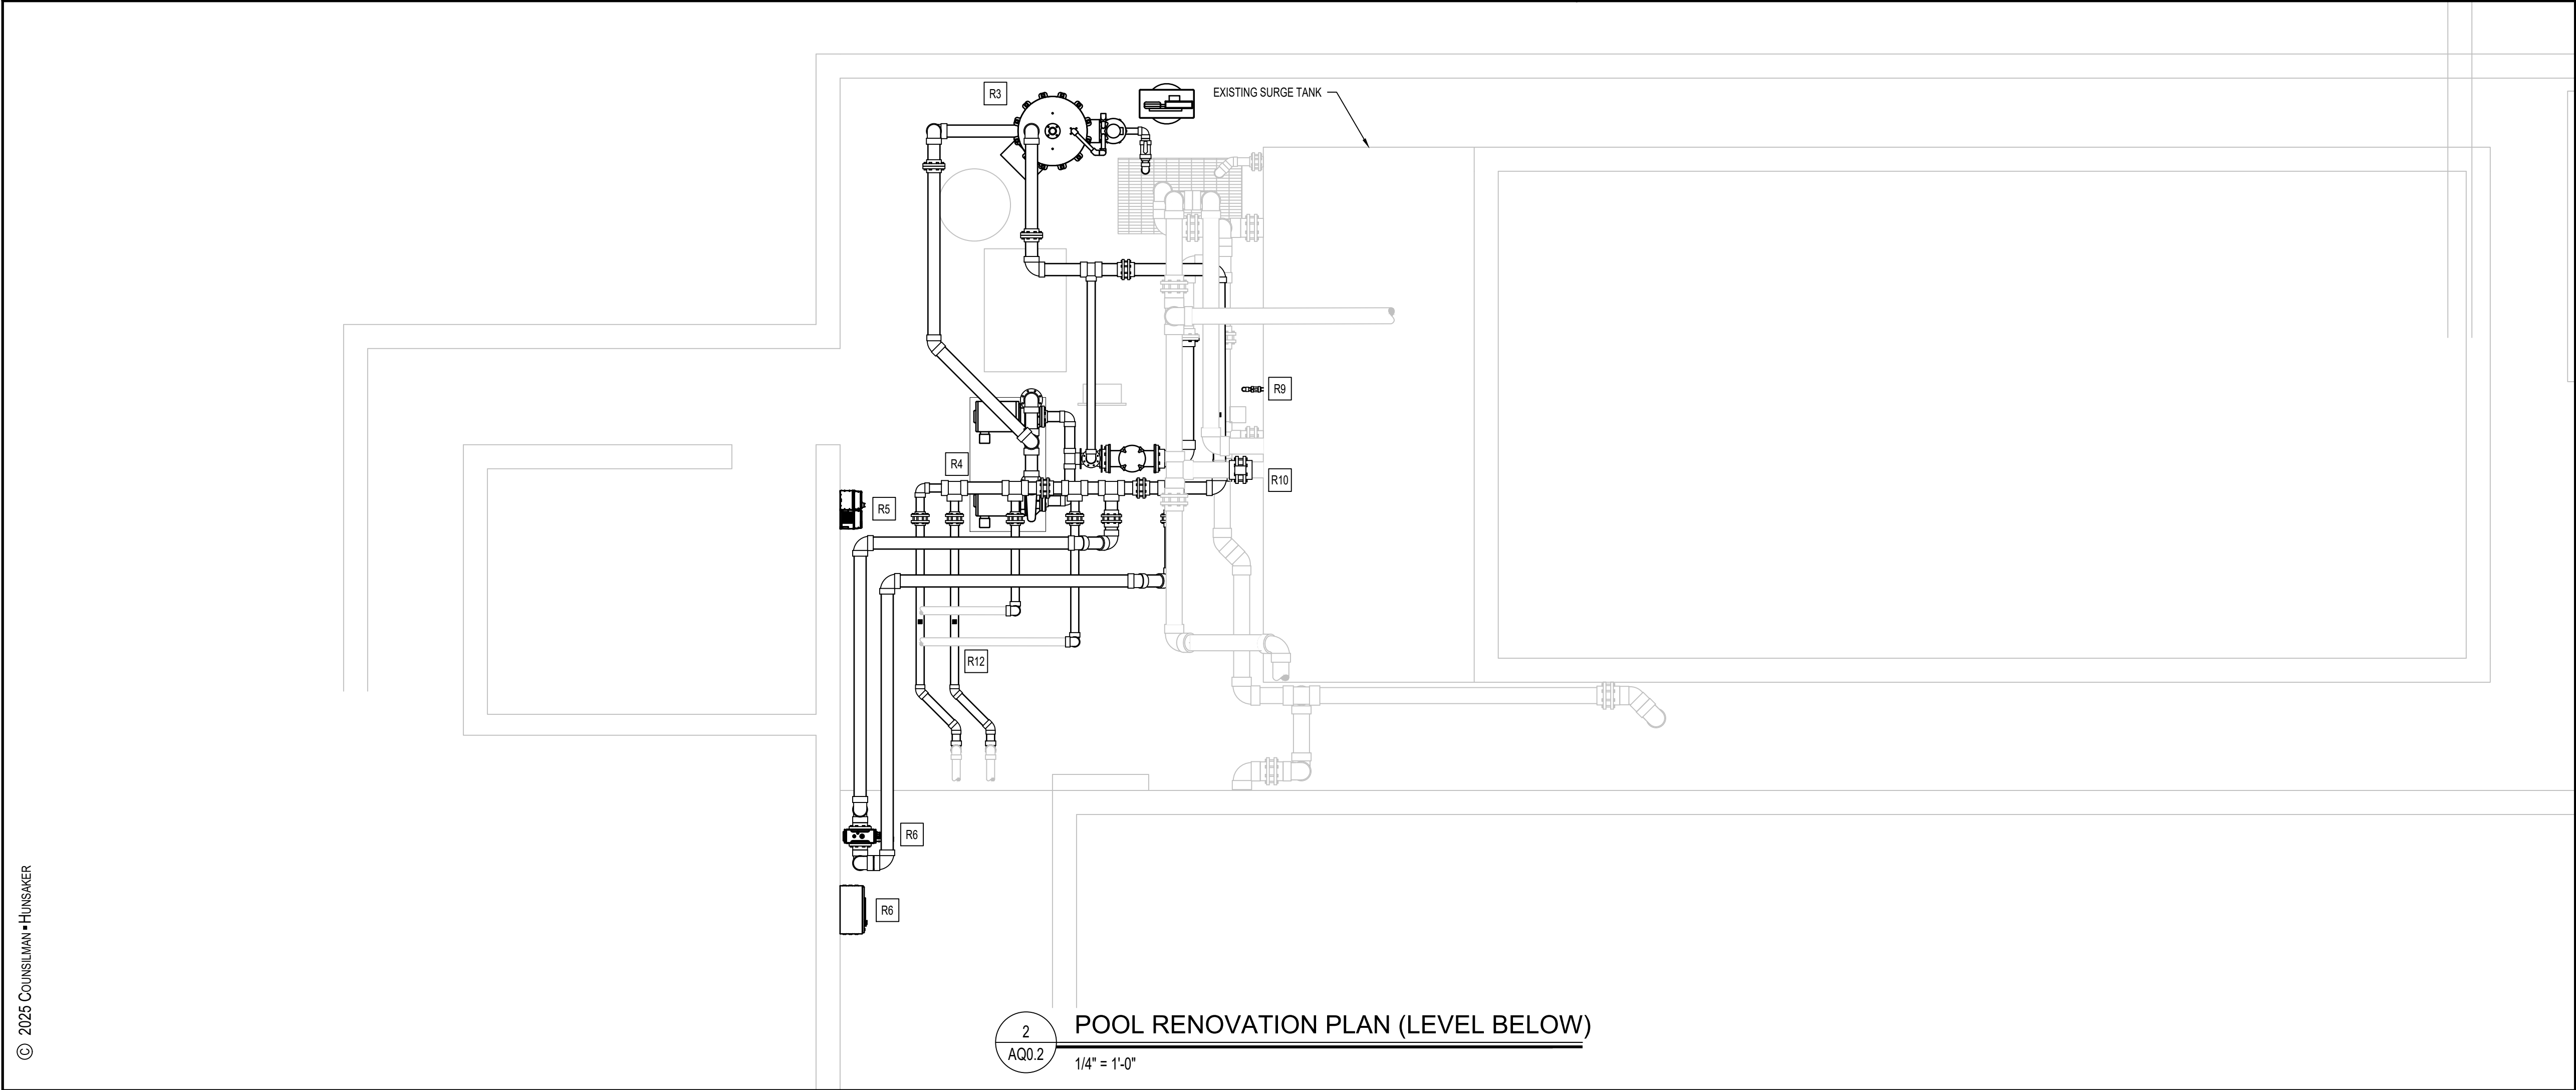

- ### GENERAL POOL DEMOLITION AND RENOVATION NOTES
- COORDINATE ALL DEMOLITION PLANS AND WORK WITH ARCHITECT AND CONSTRUCTION DOCUMENTS PRIOR TO THE START OF DEMOLITION.
 - REVIEW RECORD DOCUMENTS OF EXISTING CONSTRUCTION PROVIDED BY THE OWNER. NEITHER THE OWNER NOR ENGINEER MAKES ANY GUARANTEE THAT THE EXISTING CONDITIONS REFLECT THOSE INDICATED IN THE RECORD DOCUMENTS. CONTRACTOR TO PROVIDE NOTIFICATION OF ANY DISCREPANCIES BETWEEN EXISTING CONDITIONS AND THE CONTRACT DOCUMENTS BEFORE PROCEEDING WITH DEMOLITION.
 - CONTRACTOR TO SURVEY EXISTING CONDITIONS AND CORRELATE WITH REQUIREMENTS INDICATED IN THE CONTRACT DOCUMENTS TO DETERMINE THE EXTENT OF DEMOLITION REQUIRED. CONTRACTOR TO RECORD EXISTING CONDITIONS WITH DETAILED PRECONSTRUCTION PHOTOGRAPHS.
 - UNLESS OTHERWISE INDICATED, DEMOLITION WASTE BECOMES PROPERTY OF THE CONTRACTOR.
 - EXCEPT FOR ITEMS OR MATERIALS INDICATED TO BE RECYCLED, REUSED, SALVAGED, REINSTALLED, OR OTHERWISE INDICATED TO REMAIN OWNERS' PROPERTY, REMOVE DEMOLISHED MATERIALS FROM PROJECT SITE AND LEGALLY DISPOSE OF THEM. OWNER HAS THE FIRST RIGHT OF REFUSAL ON ALL DEMOLITION MATERIALS.
 - IF HAZARDOUS MATERIALS ARE ENCOUNTERED, DO NOT DISTURB. IMMEDIATELY NOTIFY THE OWNER AND ENGINEER.
 - INDICATE RECEIPT AND ACCEPTANCE OF ANY HAZARDOUS WASTES BY A LANDFILL FACILITY LICENSED TO ACCEPT SUCH HAZARDOUS WASTES.
 - MAINTAIN EXISTING UTILITIES TO REMAIN IN SERVICE AND PROTECT THEM AGAINST DAMAGE DURING DEMOLITION OPERATIONS. REFER TO OTHER TRADES FOR COORDINATION.
 - ELECTRICIAN MUST VERIFY EXISTING BOND GRID. ALL NEW EMBEDS AND MECHANICAL EQUIPMENT MUST BE BONDED PER NEC ARTICLE 680.
 - PROTECT ALL EXISTING POOL FINISHES, GUTTERS, MAIN DRAINS, AND ANY OTHER POOL-RELATED APPURTENANCES DURING CONSTRUCTION.
 - THE CONTRACTOR MUST BE RESPONSIBLE FOR CONTINUOUSLY MONITORING GROUNDWATER LEVELS ON THE SITE DURING ANY AND ALL PERIODS WHEN THE SWIMMING POOL IS NOT FULL OF WATER. PROTECTION OF THE EXISTING POOL STRUCTURE FROM DAMAGE DUE TO HYDROSTATIC PRESSURE IS THE SOLE RESPONSIBILITY OF THE CONTRACTOR.
 - CONTRACTOR TO PROVIDE AND EXECUTE APPROVED DUST CONTROL PLAN.
 - ALL AREAS OF WORK MUST HAVE DOUBLE CONTAINMENT AND DEDICATED EXHAUST INDEPENDENT OF HVAC.
 - CLEAN ADJACENT STRUCTURES AND IMPROVEMENTS OF DUST, DIRT, AND DEBRIS FOLLOWING DEMOLITION OPERATIONS. CONTRACTOR TO RETURN ADJACENT AREAS TO CONDITION EXISTING BEFORE THE START OF DEMOLITION OPERATIONS.

POOL RENOVATION KEYNOTES	
COORDINATE ALL DEMOLITION PLANS WITH ARCHITECT AND CONSTRUCTION DOCUMENTS PRIOR TO DEMOLITION	
R1	PERFORM ACID WASH ON EXISTING POOL TILE FINISH TO REMOVE THE CURRENT STAINING AND SURFACE CORROSION.
R2	INSTALL NEW GROUT BETWEEN THE TILES OF THE POOL FINISH. GROUT TO MATCH CONSISTENCY OF EXISTING MATERIAL. REFER TO SPECIFICATIONS.
R3	INSTALL REGENERATIVE MEDIA FILTER. REFER: 1/AQ1.2
R4	INSTALL NEW RECIRCULATION PUMPS AND STRAINER. REFER: 1/AQ1.1
R5	INSTALL VARIABLE FREQUENCY DRIVE AND BYPASS FOR NEW PUMPS.
R6	INSTALL NEW UV CHAMBER AND CABINET. REFER: 5/AQ1.1
R7	INSTALL BULK CO2 AND CO2 CONTROLLER. REFER: 3/AQ1.1
R8	INSTALL NEW CHEMICAL CONTROLLER. REFER: 2/AQ1.1
R9	INSTALL NEW WATER LEVEL CONTROLLER. REFER: 10/AQ1.1
R10	INSTALL ELECTRICALLY ACTUATED VALVES. REFER: 8/AQ1.2 & 1/AQ2.0
R11	INSTALL NEW VGB COVERS AT THE FOUR (4) MAIN DRAIN SUMPS. REFER: 9/AQ1.2
R12	INSTALL NEW FLOW SENSORS. REFER: 7/AQ1.1

KEY PLAN	
ISSUE DATE	ISSUED FOR
02/19/2025	BIDS
DRAWN	ZRW
CHECKED	ALJ
APPROVED	CPN

FRENCH

2851 High Meadow Circle | Suite 100
Auburn Hills | MI 48326
248.656.1377

COUNSILMAN•HUNSAKER
AQUATICS FOR LIFE
ph: 314.894.1246 • www.chh2o.com

PROJECT

Livonia Public Schools
Stevenson High School
Pool Filtration Project

LIVONIA,
MICHIGAN

SHEET


POOL
MECHANICAL
ROOM
RENOVATION
PLANS

PROJECT NUMBER

2024-081

SHEET NUMBER

AQ0.2

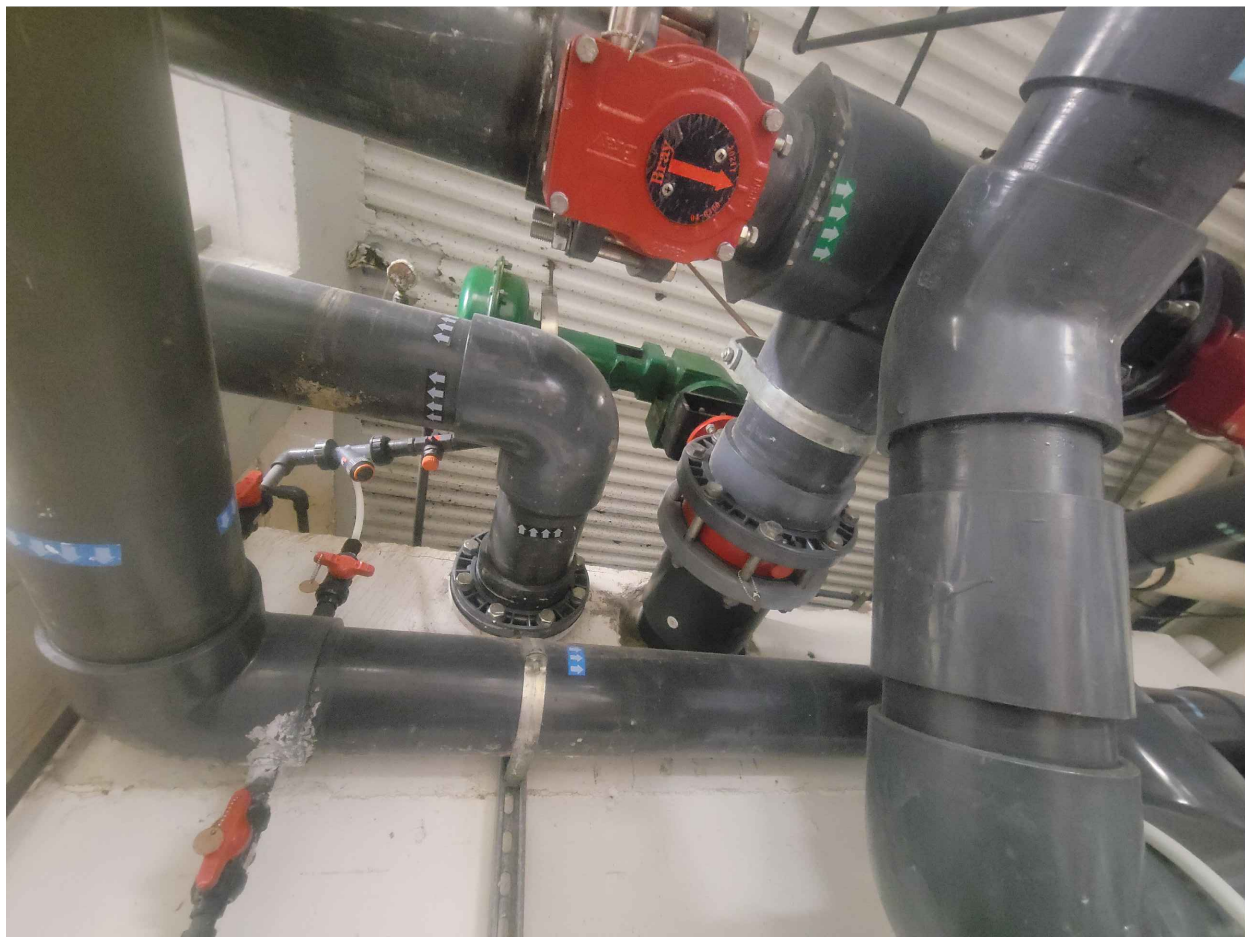

10
AQ0.3
EXISTING GUTTER FISHER VALVE
NTS



7
AQ0.3
EXISTING FLOW METER SENSORS
NTS



4
AQ0.3
EXISTING SAND FILTERS
NTS



1
AQ0.3
OVERALL MECHANICAL ROOM (LEVEL BELOW)
NTS




11
AQ0.3
EXISTING CHEMICAL INJECTIONS
NTS



8
AQ0.3
EXISTING UV CHAMBER & CABINET
NTS




5
AQ0.3
EXISTING PUMP MOTOR STARTER
NTS

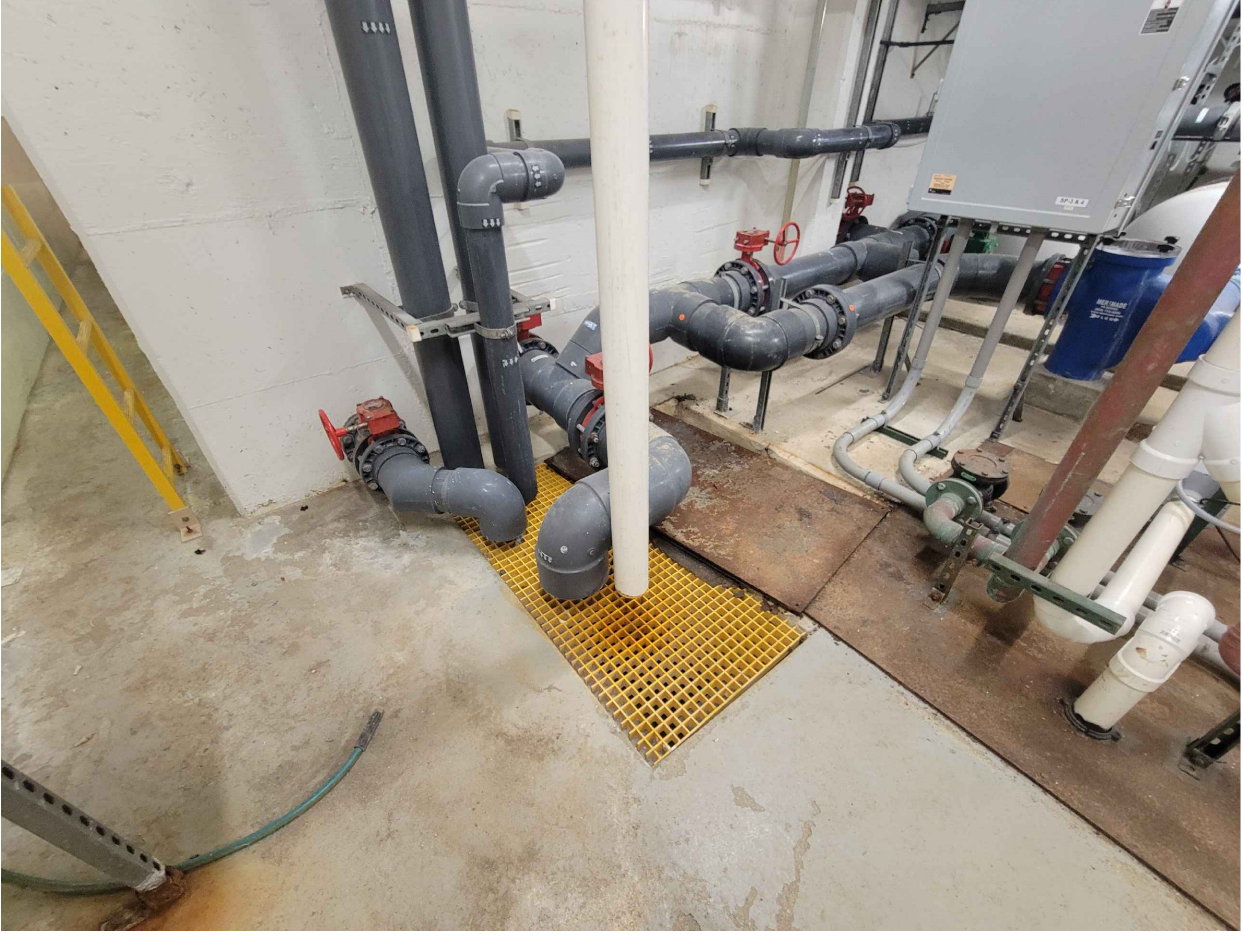


2
AQ0.3
EXISTING BACKWASH CATCH BASIN TO REMAIN
NTS




12
AQ0.3
EXISTING WATER LEVEL PIPE FOR NEW SENSORS
NTS

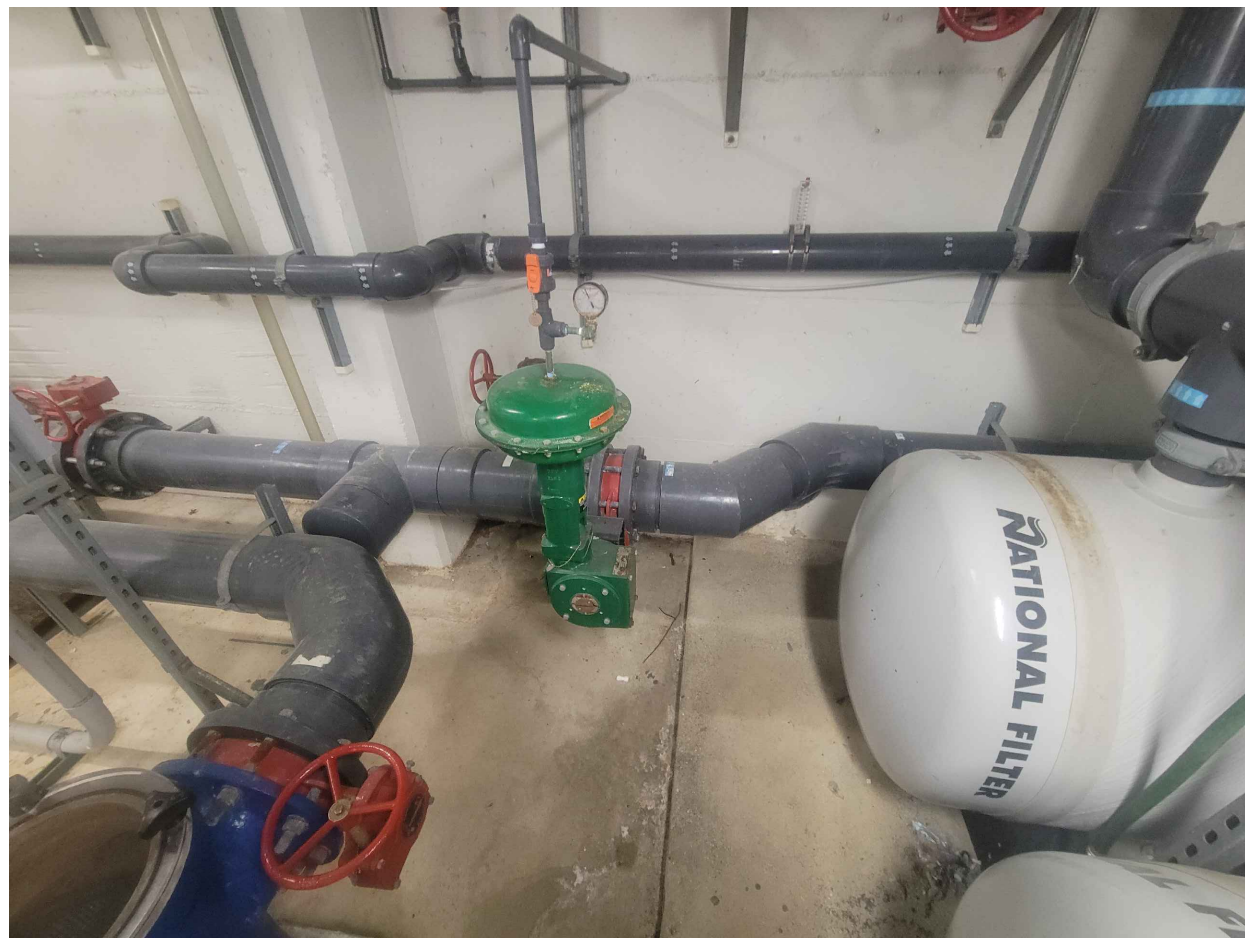

9
AQ0.3
EXISTING MAIN DRAIN FISHER VALVE
NTS

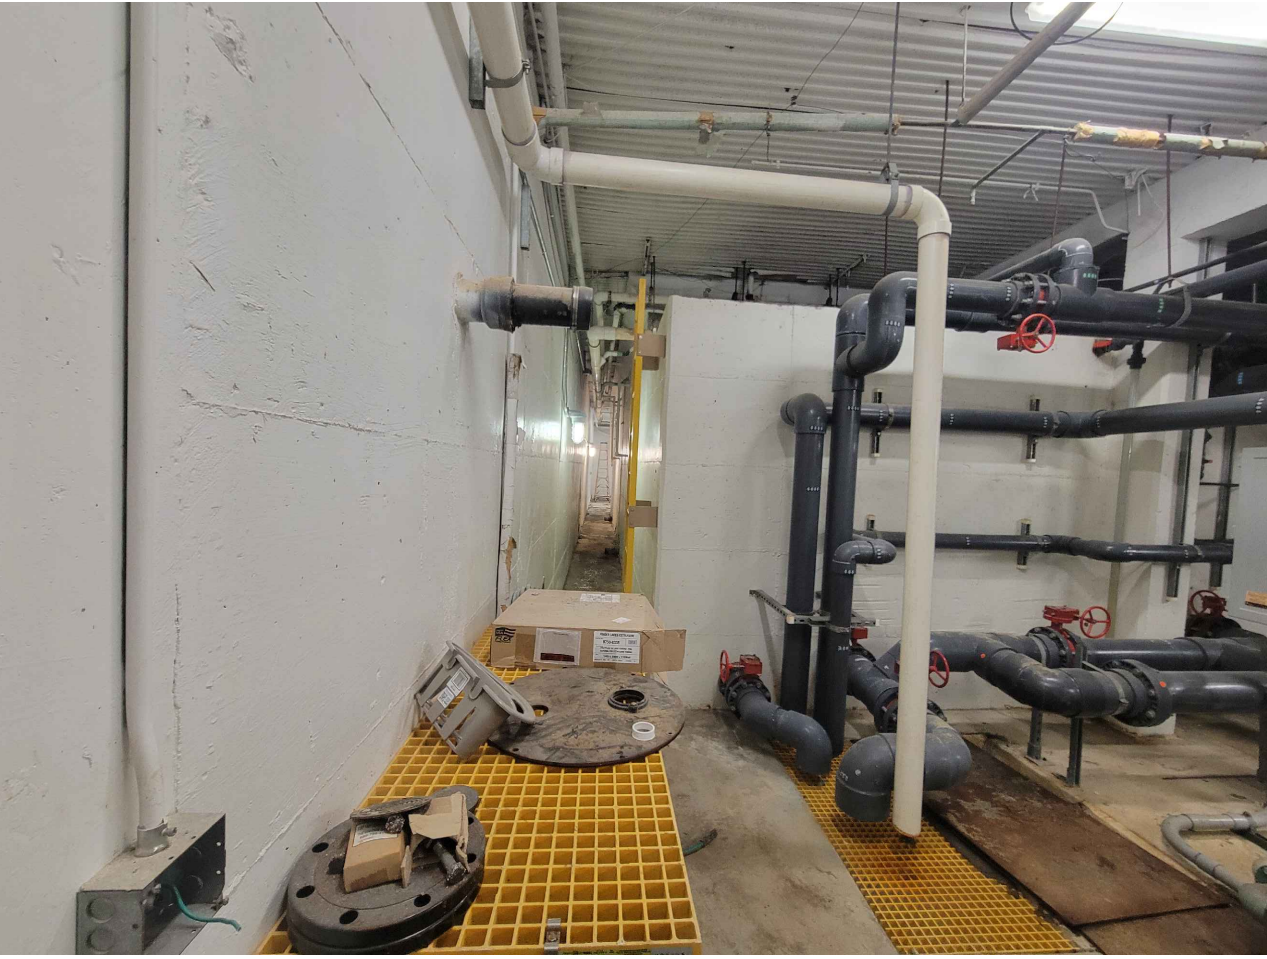

6
AQ0.3
EXISTING YELLOW GRATING SHELF
NTS

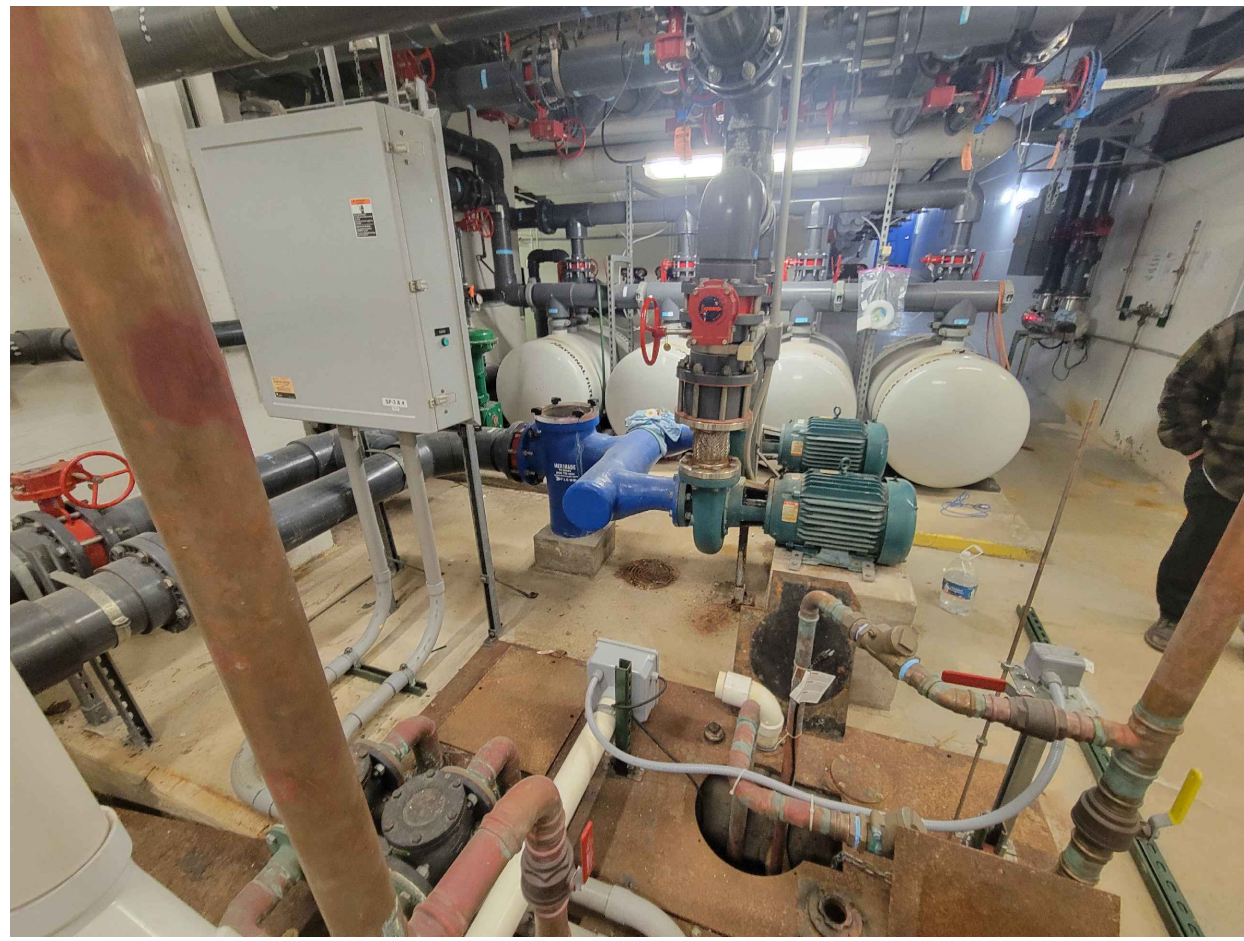


3
AQ0.3
EXISTING RECIRCULATION PUMPS & STRAINER
NTS

KEY PLAN	
ISSUE DATE	ISSUED FOR
02/19/2025	BIDS
DRAWN	ZRW
CHECKED	ALJ
APPROVED	CPN



FRENCH

2851 High Meadow Circle | Suite 100
Auburn Hills | MI 48326
248.656.1377

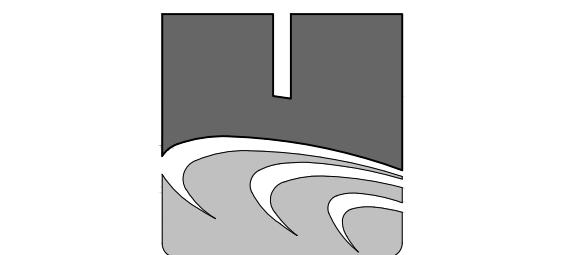

COUNSLMAN-HUNSAKER
AQUATICS FOR LIFE
ph: 314.894.1246 - www.chh2o.com

PROJECT

Livonia Public Schools
Stevenson High School
Pool Filtration Project

LIVONIA,
MICHIGAN

SHEET

POOL
MECHANICAL
ROOM
EXISTING
CONDITIONS

PROJECT NUMBER

2024-081

SHEET NUMBER


AQ0.3



4
AQ0.4

EXISTING DIVE POOL MAIN DRAIN COVERS


NTS

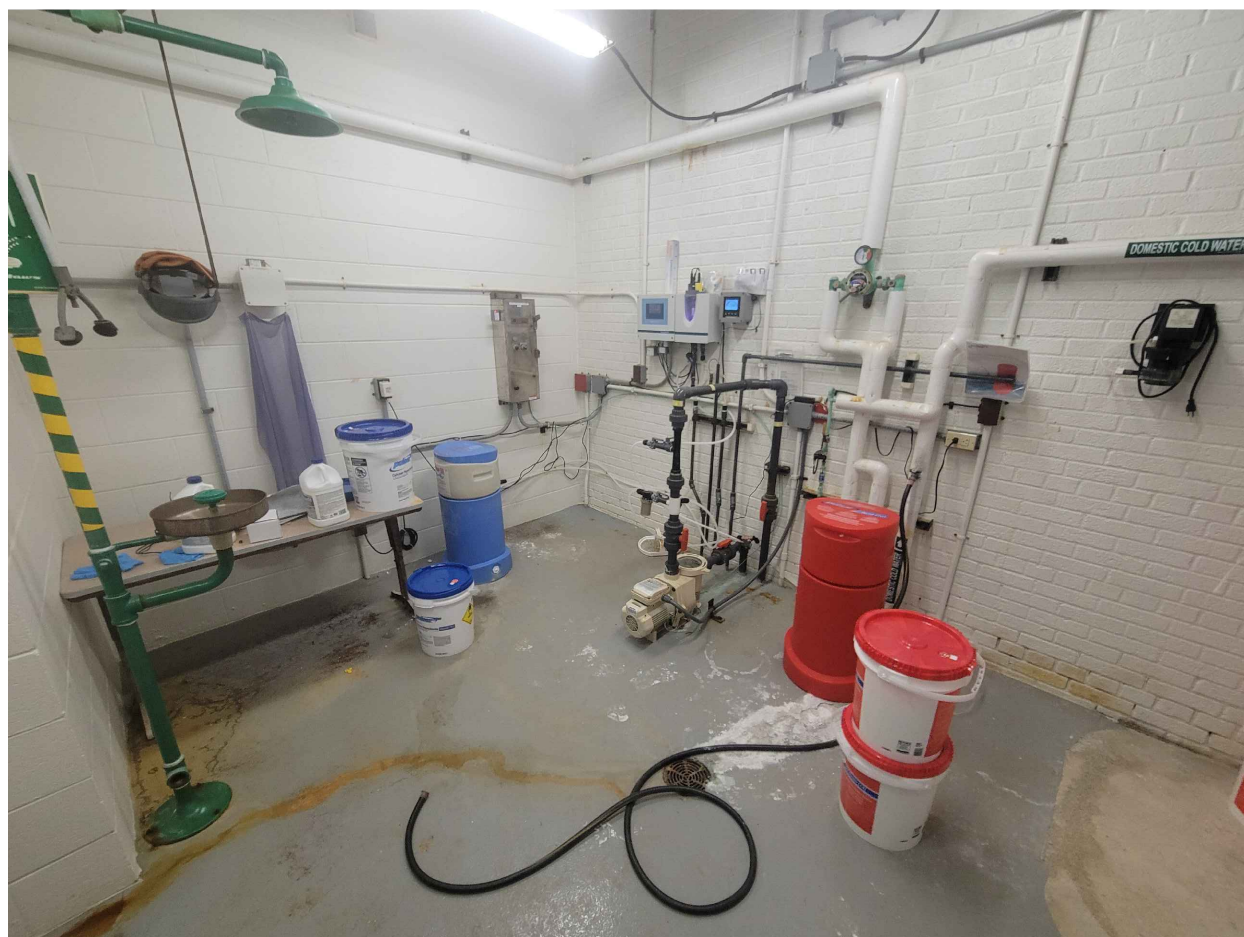

1
AQ0.4

OVERALL MECHANICAL ROOM (MAIN LEVEL)


NTS

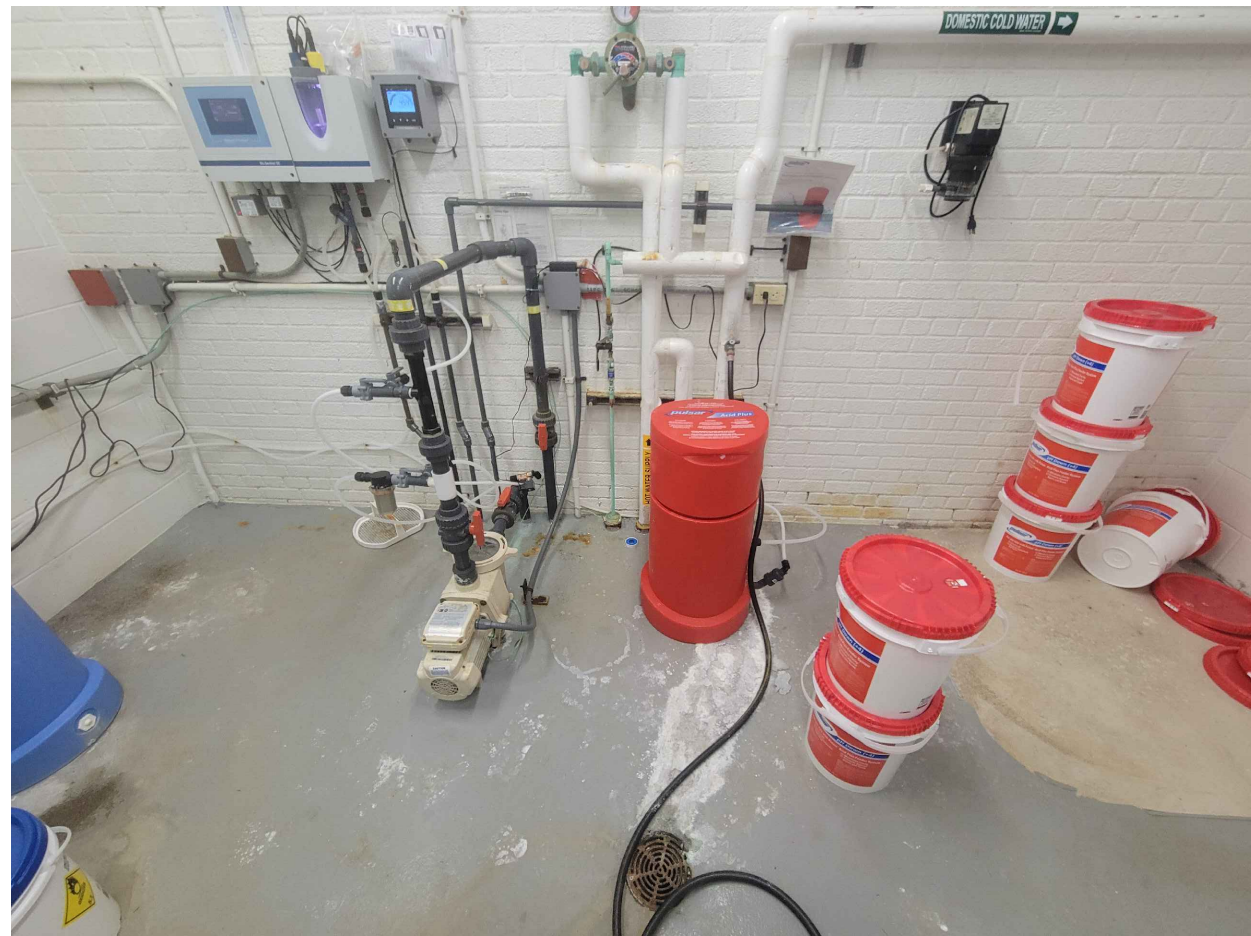

2
AQ0.4

EXISTING CHEMICAL CONTROLLER

NTS

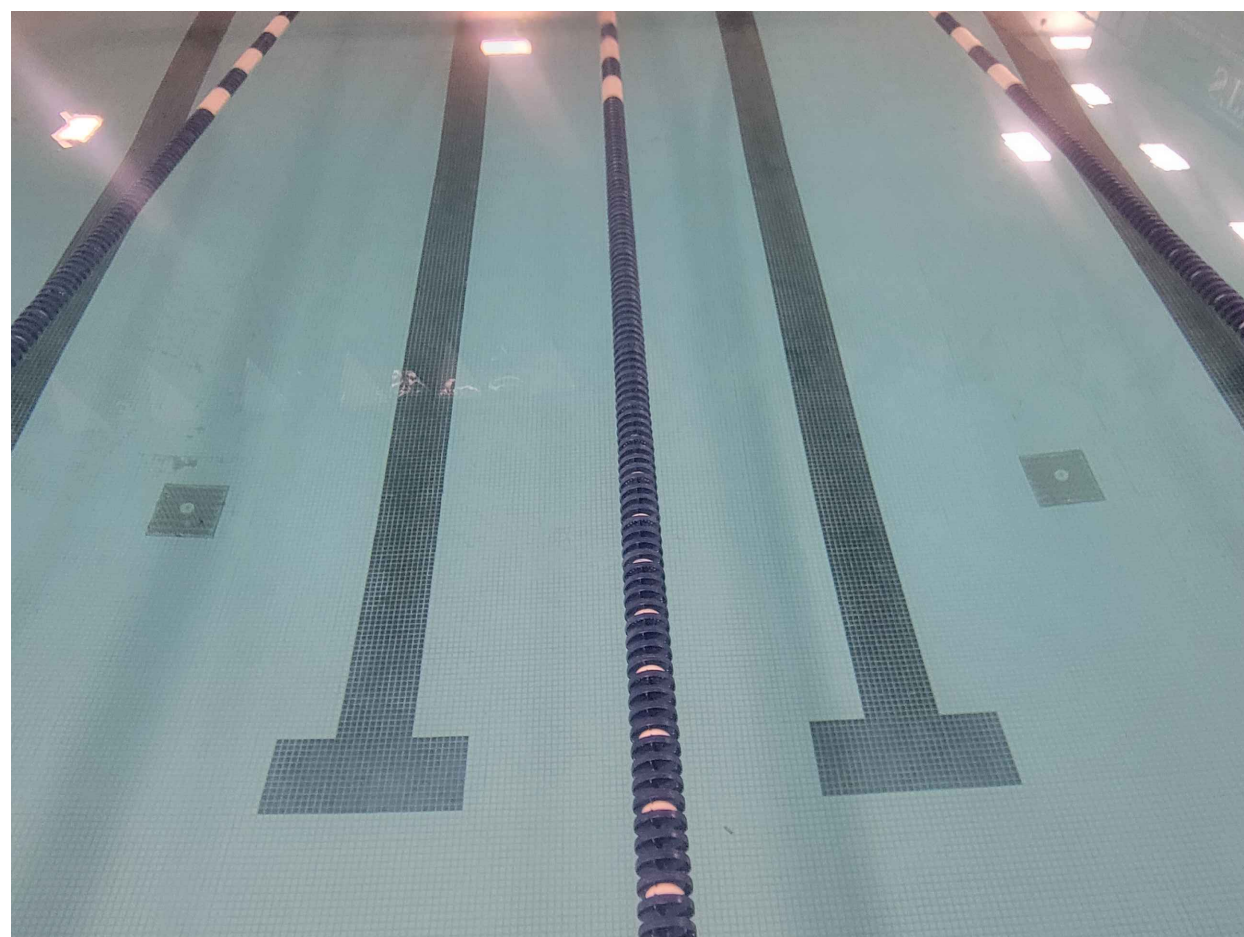

3
AQ0.4

EXISTING LAP POOL MAIN DRAIN COVERS

NTS

KEY PLAN

ISSUE DATE

02/19/2025

ISSUED FOR

BIDS

DRAWN

ZRW

CHECKED

ALJ

APPROVED

CPN

FRENCH

2851 High Meadow Circle | Suite 100
Auburn Hills | MI 48326
248.656.1377

COUNSILMAN • HUNSAKER
AQUATICS FOR LIFE
ph: 314.894.1246 • www.chh2o.com

PROJECT

Livonia Public Schools
Stevenson High School
Pool Filtration Project

LIVONIA,
MICHIGAN

SHEET

POOL
MECHANICAL
ROOM
EXISTING
CONDITIONS

PROJECT NUMBER

2024-081

SHEET NUMBER

AQ0.4



EQUIPMENT SCHEDULE	
ID	ITEM
1	CHEMICAL CONTROLLER REFER: 2/AQ1.1
2	WATER LEVEL CONTROLLER REFER: 10/AQ1.1
3	VARIABLE FREQUENCY DRIVE AND BYPASS PANEL
4	IMPACT FLOW METER REFER: 8/AQ1.1
5	EXISTING BACKWASH CATCH BASIN REFER: 2/AQ0.3
6	CO2 TANK REFER: 3/AQ1.1
7	AIR COMPRESSOR
8	UV TEE REFER: 10/AQ1.2
9	HEATER TEE REFER: 10/AQ1.2
10	CHEMICAL TAP REFER: 8/AQ1.1
11	ELECTRICALLY ACTUATED VALVE REFER: 8/AQ1.2
12	FLOW METER SENSOR REFER: 7/AQ1.1

FILTER SCHEDULE											
ID	POOL	MANUFACTURER	FILTER MODEL	QTY.	FILTRATION TYPE	MAXIMUM FILTRATION RATE (GPM/SQ. FT)	DESIGN FILTRATION RATE (GPM/SQ.FT.)	REQUIRED FILTRATION AREA (SQ. FT.)	DESIGN FILTRATION AREA (SQ. FT.)	FILTER TANK VOLUME (GAL)	DRAIN FLOW RATE PER FILTER (GPM)
FI	LAP/DIVE	DEFENDER	SP-33-48-732	1	RMF	1.3	0.95	416.9	572.0	250	300
<p>NOTE:</p> <p>1. DRAIN METHOD MUST BE MANUAL.</p> <p>2. ALL FILTER SUPPORTS MUST BE SEISMICALLY RATED FOR THE SEISMIC ZONE IN WHICH IT IS INSTALLED IN ACCORDANCE WITH LOCAL AND/OR STATE REQUIREMENTS.</p> <p>3. FILTER MANUFACTURER MUST CERTIFY FILTER MEDIA.</p> <p>4. THE DRAIN PIPING MUST TERMINATE NO CLOSER THAN 6" ABOVE THE FLOOD RIM OF THE DRAIN BASIN OR TWICE THE PIPE DIAMETER, WHICHEVER IS GREATER.</p> <p>5. FILTER TANK ASSEMBLIES MUST BEAR THE NATIONAL SANITATION FOUNDATION SEAL OF APPROVAL FOR A MAXIMUM FLOW RATE 20 GPM PER SQUARE FOOT OF FILTER MEDIA.</p> <p>6. THE BACKWASH THROTTLING VALVE/S HANDLE MUST BE REMOVED AND TURNED OVER TO THE OWNER ONCE THE BACKWASH FLOW RATE/S HAVE BEEN TESTED, ADJUSTED AND BALANCED.</p> <p>7. PROVIDE 1" DIAMETER, SCHEDULE 80 PIPE FROM THE AUTOMATIC AIR VENT ON EACH OF THE FILTER VESSEL TO THE NEAREST FLOOR DRAIN OR BACKWASH WATCH BASIN. THE VENT PIPE MUST BE SLOPED TO THE DRAIN.</p> <p>8. FILTER TANK ASSEMBLIES MUST BEAR THE NATIONAL SANITATION FOUNDATION SEAL OF APPROVAL FOR A MAXIMUM FLOW RATE OF 1.6 GPM PER SQUARE FOOT OF FILTER MEDIA.</p> <p>9. PROVIDE HARD PLUMBED SCHEDULE 80 PIPE FROM BOTTOM OF THE FILTER TANK TO DRAIN BASIN IN ORDER TO DRAIN TANK AND MEDIA ON AN NEEDS BASIS. PIPE SLOPED FROM FILTER TANK TO WASTE PIT.</p> <p>10. VALVES MUST BE PROVIDED TO DRAIN EACH FILTER INDEPENDENTLY.</p> <p>11. PROVIDE NON-HAZARDOUS, NON-TOXIC, FILTER MEDIA, PARTICLE SIZE MUST HAVE MEDIAN PORE SIZE OF NO GREATER THAN 20 MICRONS.</p> <p>12. REFER: 1/AQ1.2</p>											

PUMP SCHEDULE									
ID	DESCRIPTION	MANUFACTURER	MODEL	SIZE	GPM	TDH	HP	NPSHR	HAIR/LINT MAKE
PP1	LAPIDIVE POOL RECIRCULATION PUMP 1 REFER: 1/AQ.1	AURORA	3801	4"X3"	542	73	15.0	8.3	MER-MADE
PP2	LAPIDIVE POOL RECIRCULATION PUMP 2 REFER: 1/AQ.1	AURORA	3801	4"X3"	542	73	15.0	8.3	MER-MADE

NOTE:

1. THE MANUFACTURER INDICATED IS BASIS OF DESIGN. PUMP MANUFACTURERS: GRISWOLD, HERBORN, PACO OR AURORA MUST BE CONSIDERED EQUAL PROVIDED THEY MEET SPECIFICATIONS AS INDICATED IN BID DOCUMENTS.
2. POOL PUMPS AND STRAINERS MUST BE INSTALLED ON HOUSEKEEPING PADS.
3. PROVIDE INFLUENT AND EFFLUENT GAUGES FOR EACH PUMP. PRESSURE GAUGES HAVE A RANGE OF 0-60 PSI. COMPOUND GAUGES HAVE A RANGE OF 0-30 HG / 0-60 PSI.
4. PROVIDE WITH 460 VOLT, 3 PHASE, 60HZ, 1800 RPM MOTOR.
5. PROVIDE WITH CHECK VALVE.
6. PROVIDE VARIABLE FREQUENCY DRIVE & BYPASS.

UV TREATMENT SYSTEMS SCHEDULE						
ID	POOL	MODEL NUMBER	CALCULATED 60 MU/CM2 (GPM)	LAMPS	POWER (KW)	VOLTAGE (V) WITH BREAKER SIZE (50 OR 60 HZ)
U1	LAP/DIVE	WF-125-6-N	616	1 @ 2.5KW	2.5	208 V (1Φ)-30A 220 V (1Φ)-30A 230 V (1Φ)-30A 240 V (1Φ)-30A

NOTE:

1. THE BASIS OF DESIGN MANUFACTURER IS ETS.
2. INTERLOCK UV SYSTEM WITH CHEMICAL CONTROLLER OR RECIRCULATION PUMP.
3. REFER: 5/AQ1.1

CHEMICAL FEED SCHEDULE					
ID	DESCRIPTION	MANUFACTURER	MODEL	FLOW	NOTES
CF1	EXISTING CHLORINATION BOOSTER PUMP TO REMAIN	PULSAR	PRECISION 30	36 LBS/DAY	N/A
CF2	EXISTING ACID FEED PUMP TO REMAIN	PULSAR	ACID PLUS	60 LBS/DAY	N/A
CF3	CO2 FEED REFER: 3FAQ1.1	PROMINENT	CO2-200	20-200 SCFH	1,2,3,4
NOTE: 1. THE MANUFACTURER INDICATED IS BASIS OF DESIGN. ALTERNATE MANUFACTURER: BECS, EK03 OR APPROVED EQUAL. 2. PROVIDE WITH 120 VOLT, SINGLE PHASE, ADJUSTABLE FEED. 3. INTERLOCK WITH POOL RECIRCULATION PUMP. 4. INTERLOCK CHEMICAL FEED PUMP WITH FILTER TO PREVENT FEEDING DURING PRE-COAT CYCLE.					

ISSUE DATE	ISSUED FOR
02/19/2025	BIDS
DRAWN	ZRW
CHECKED	ALJ
APPROVED	CPN

FRENCH
2851 High Meadow Circle | Suite 100
Auburn Hills | MI 48326
248.656.1377

COUNSILMAN • HUNSAKER
AQUATICS FOR LIFE
ph: 314.894.1245 • www.chh2o.com

PROJECT

Livonia Public Schools
Stevenson High School
Pool Filtration Project

LIVONIA,
MICHIGAN

1 SHEET




POOL MECHANICAL ROOM PLANS

PROJECT NUMBER













2024-081

SHEET NUMBER

AQ1.0

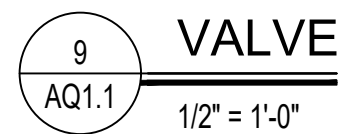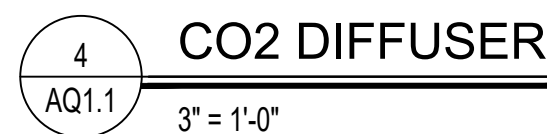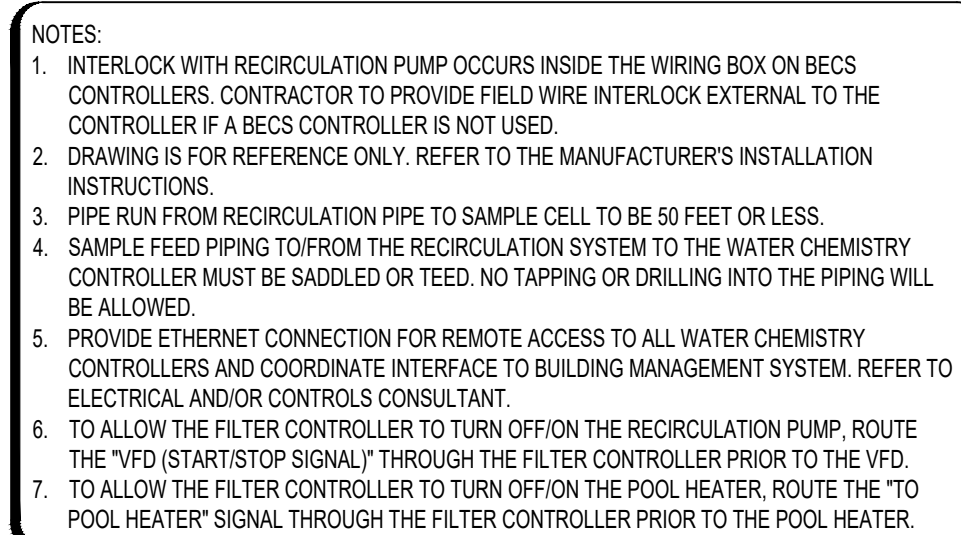

AQ1.1

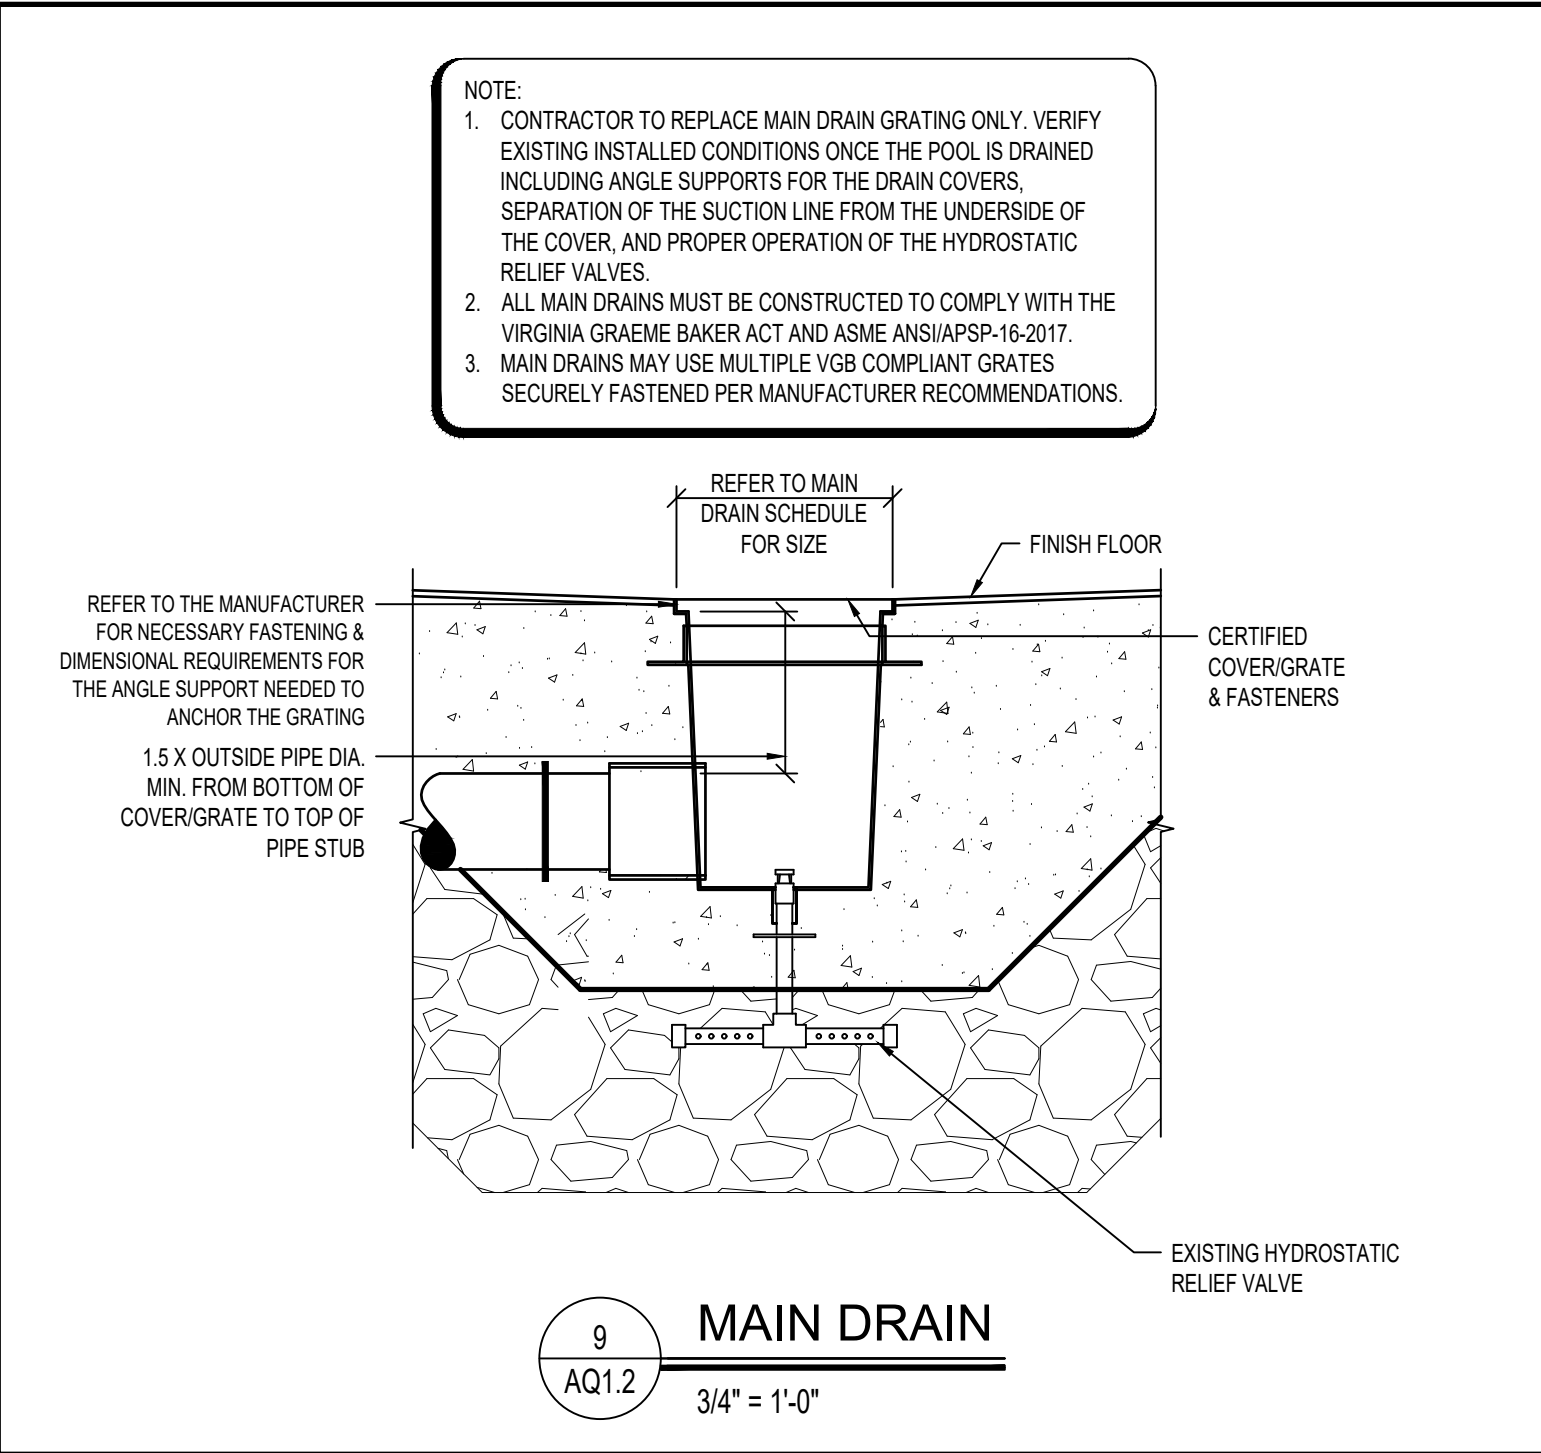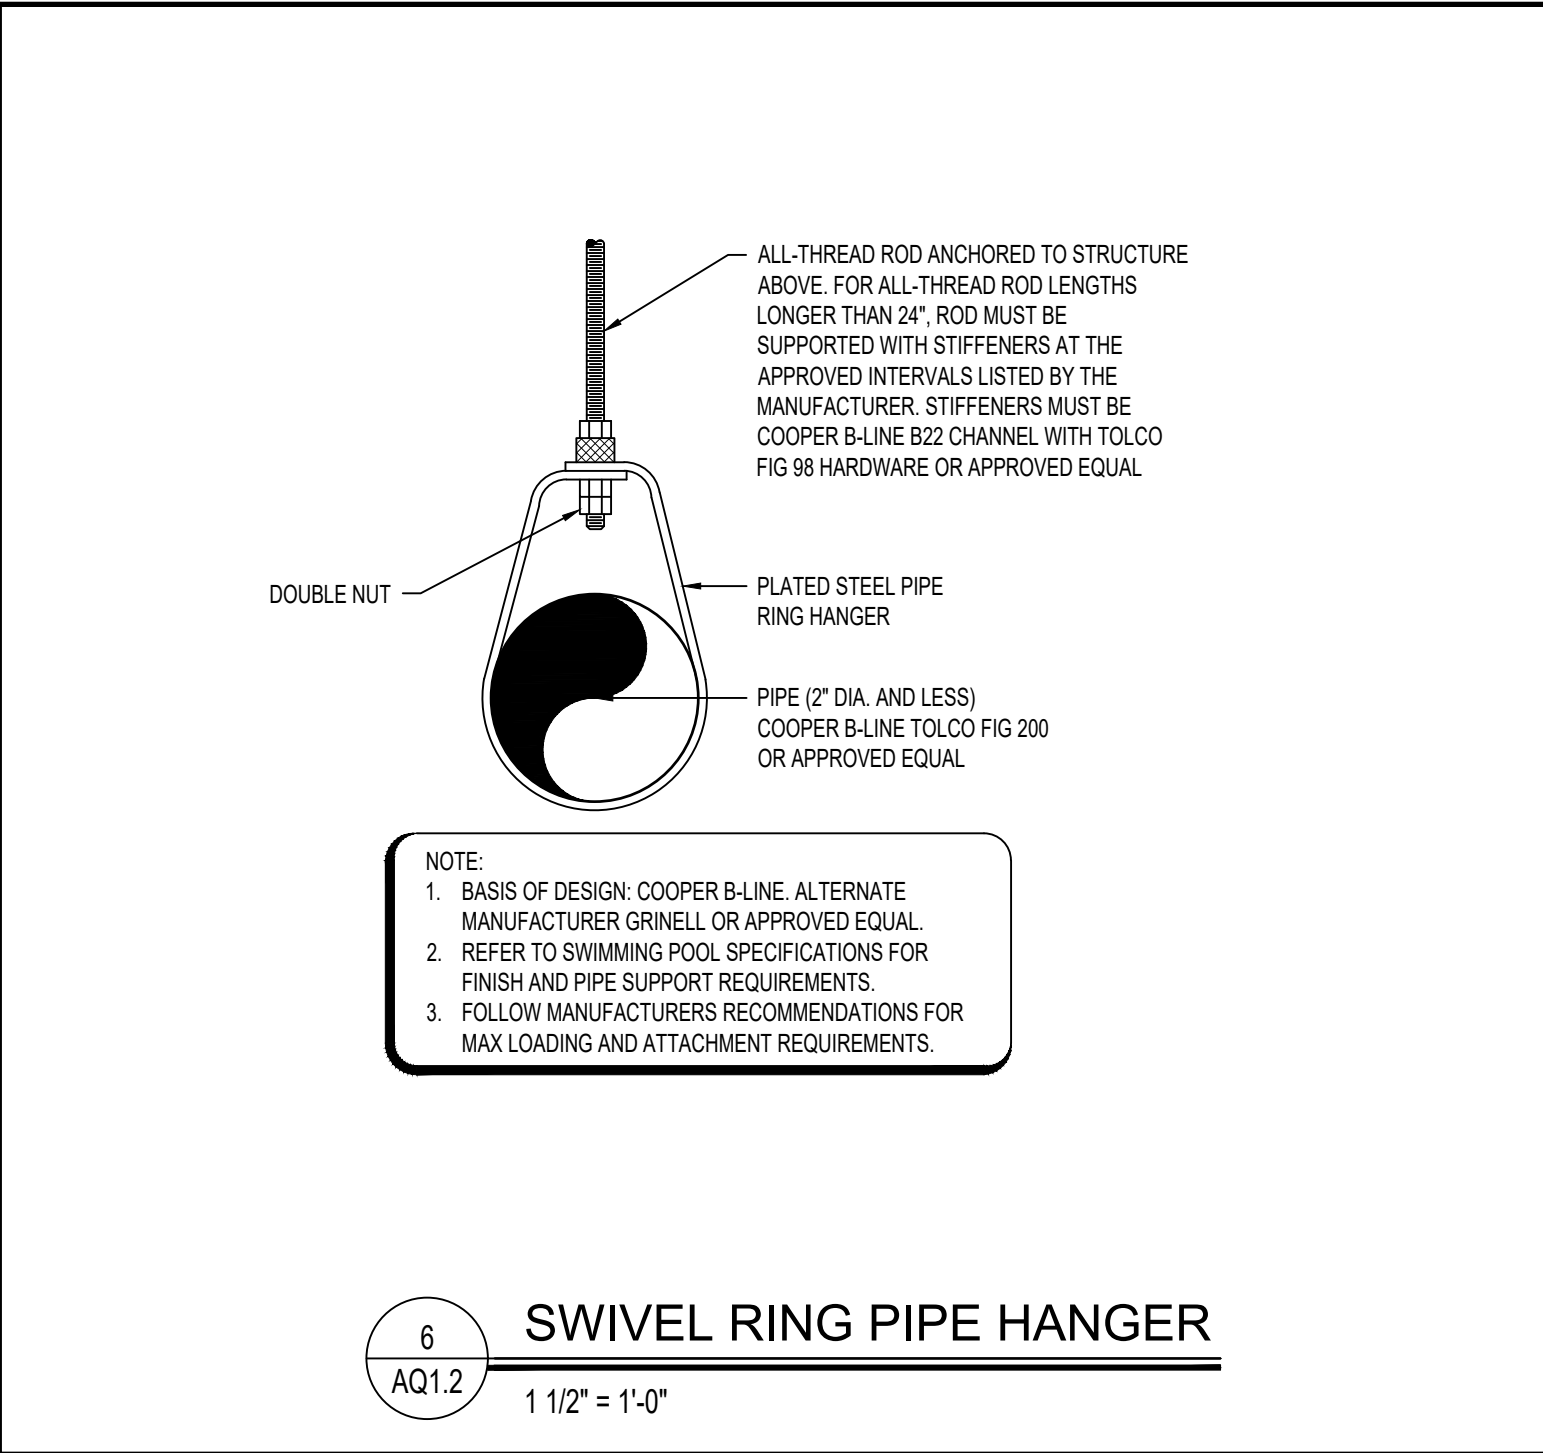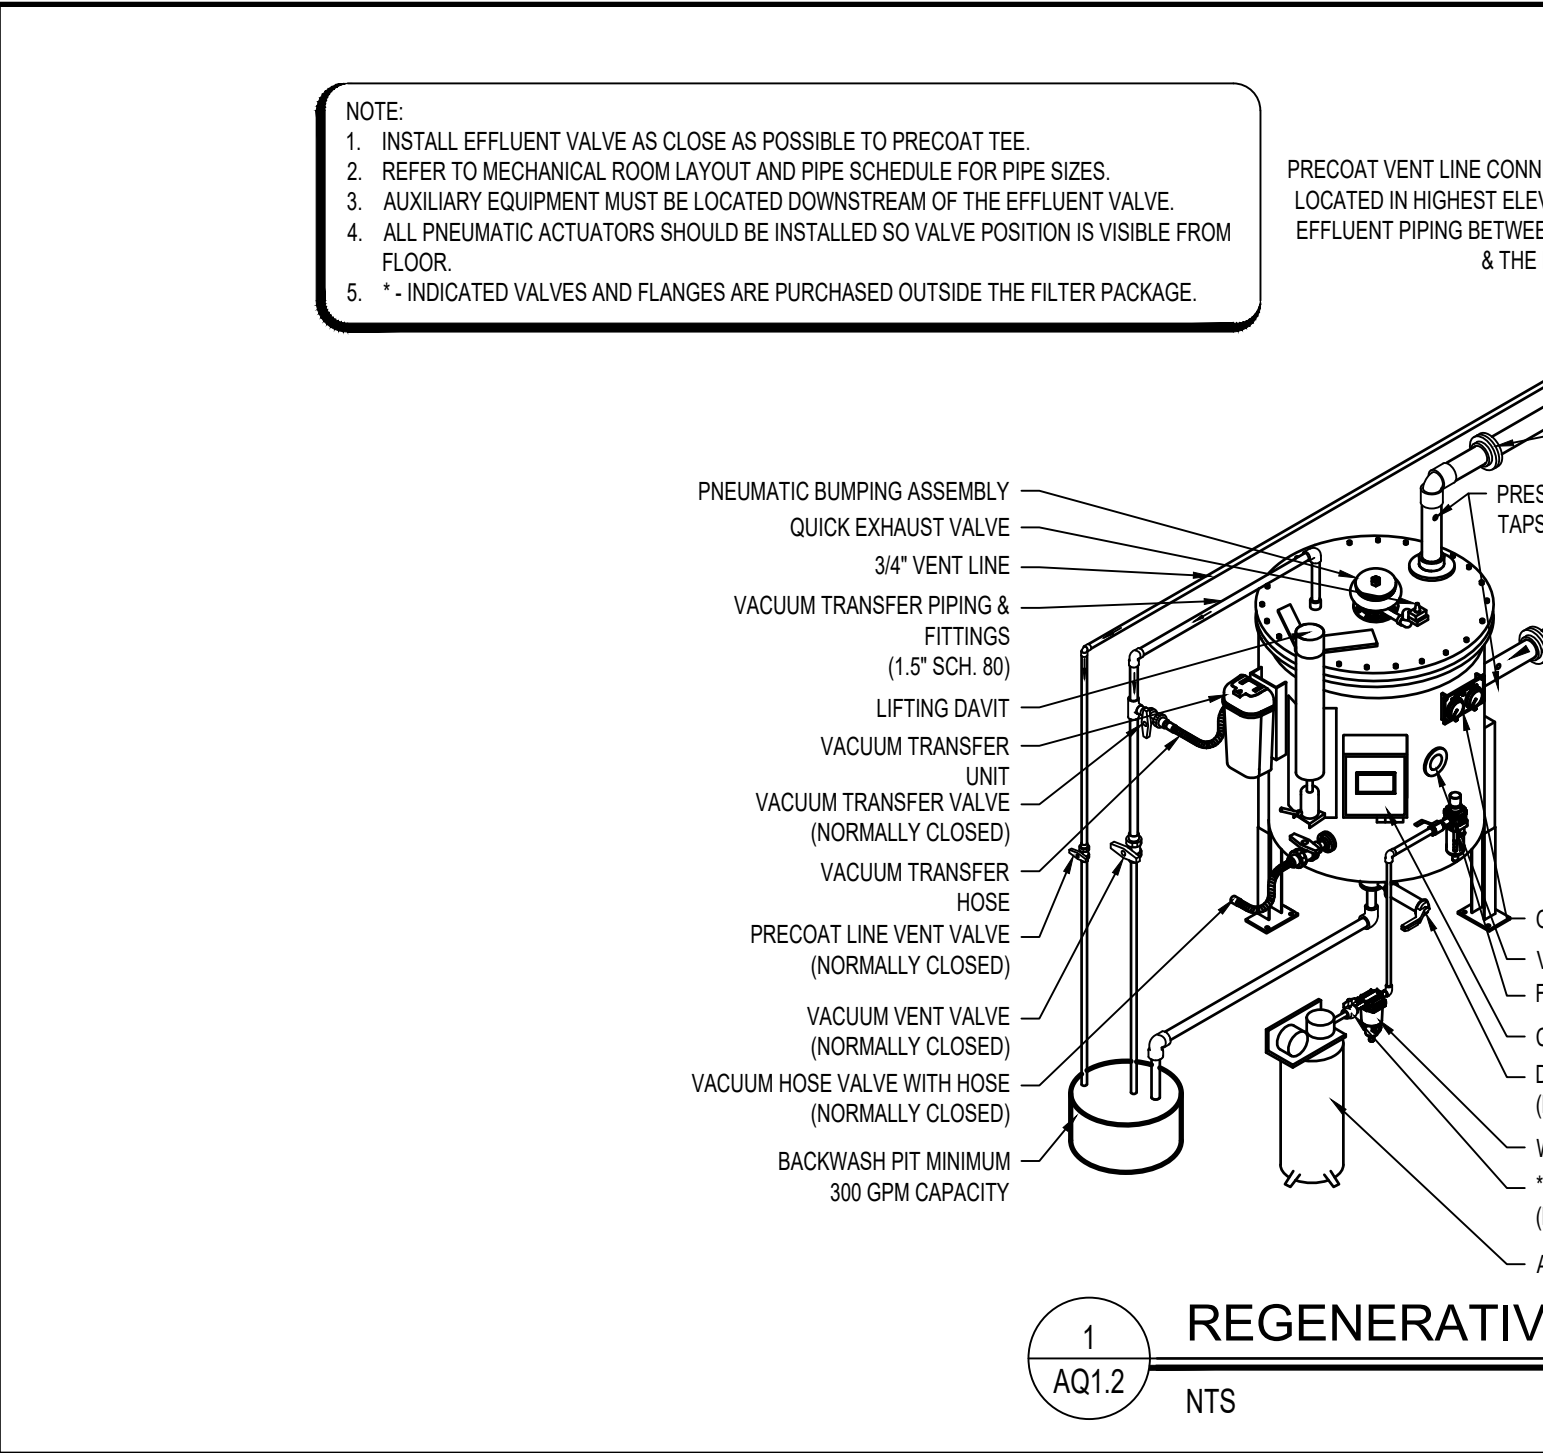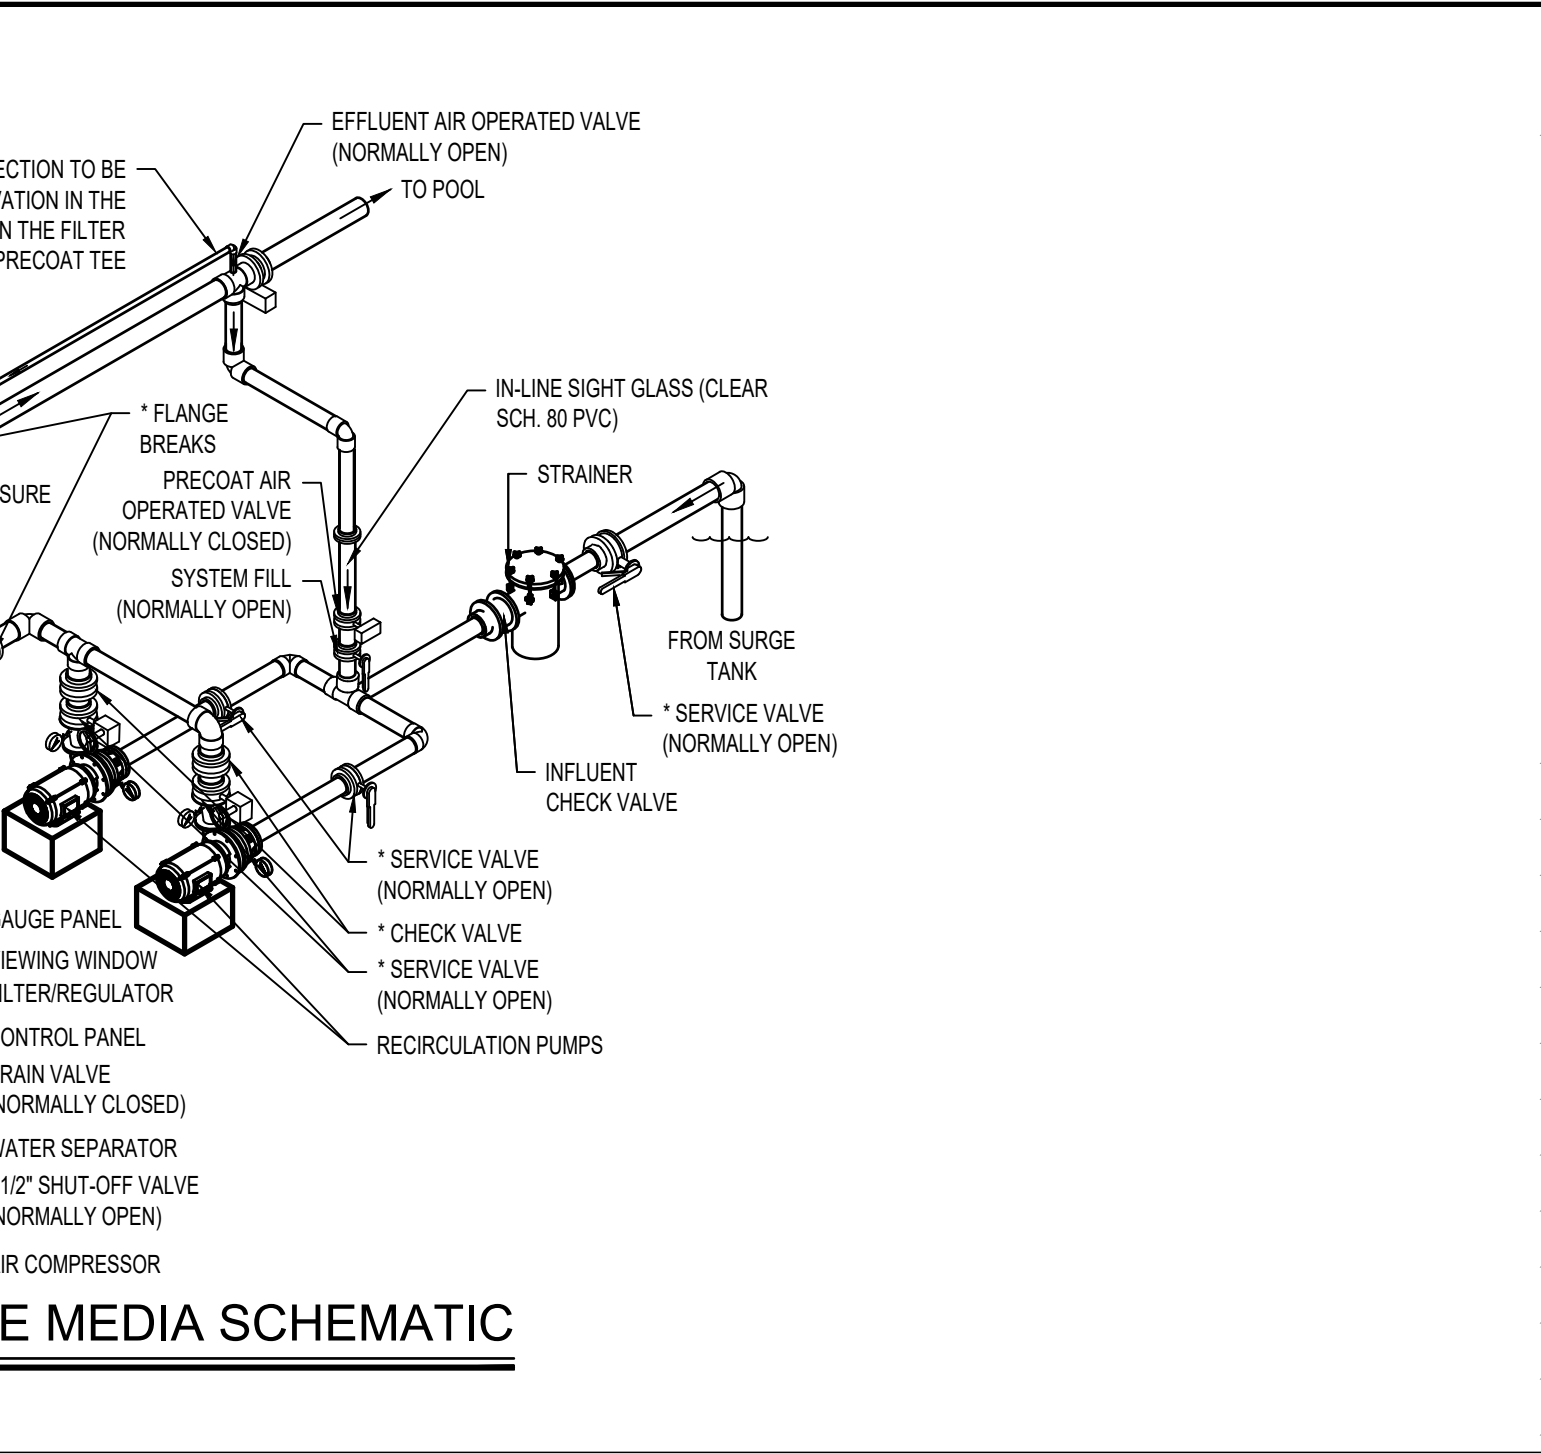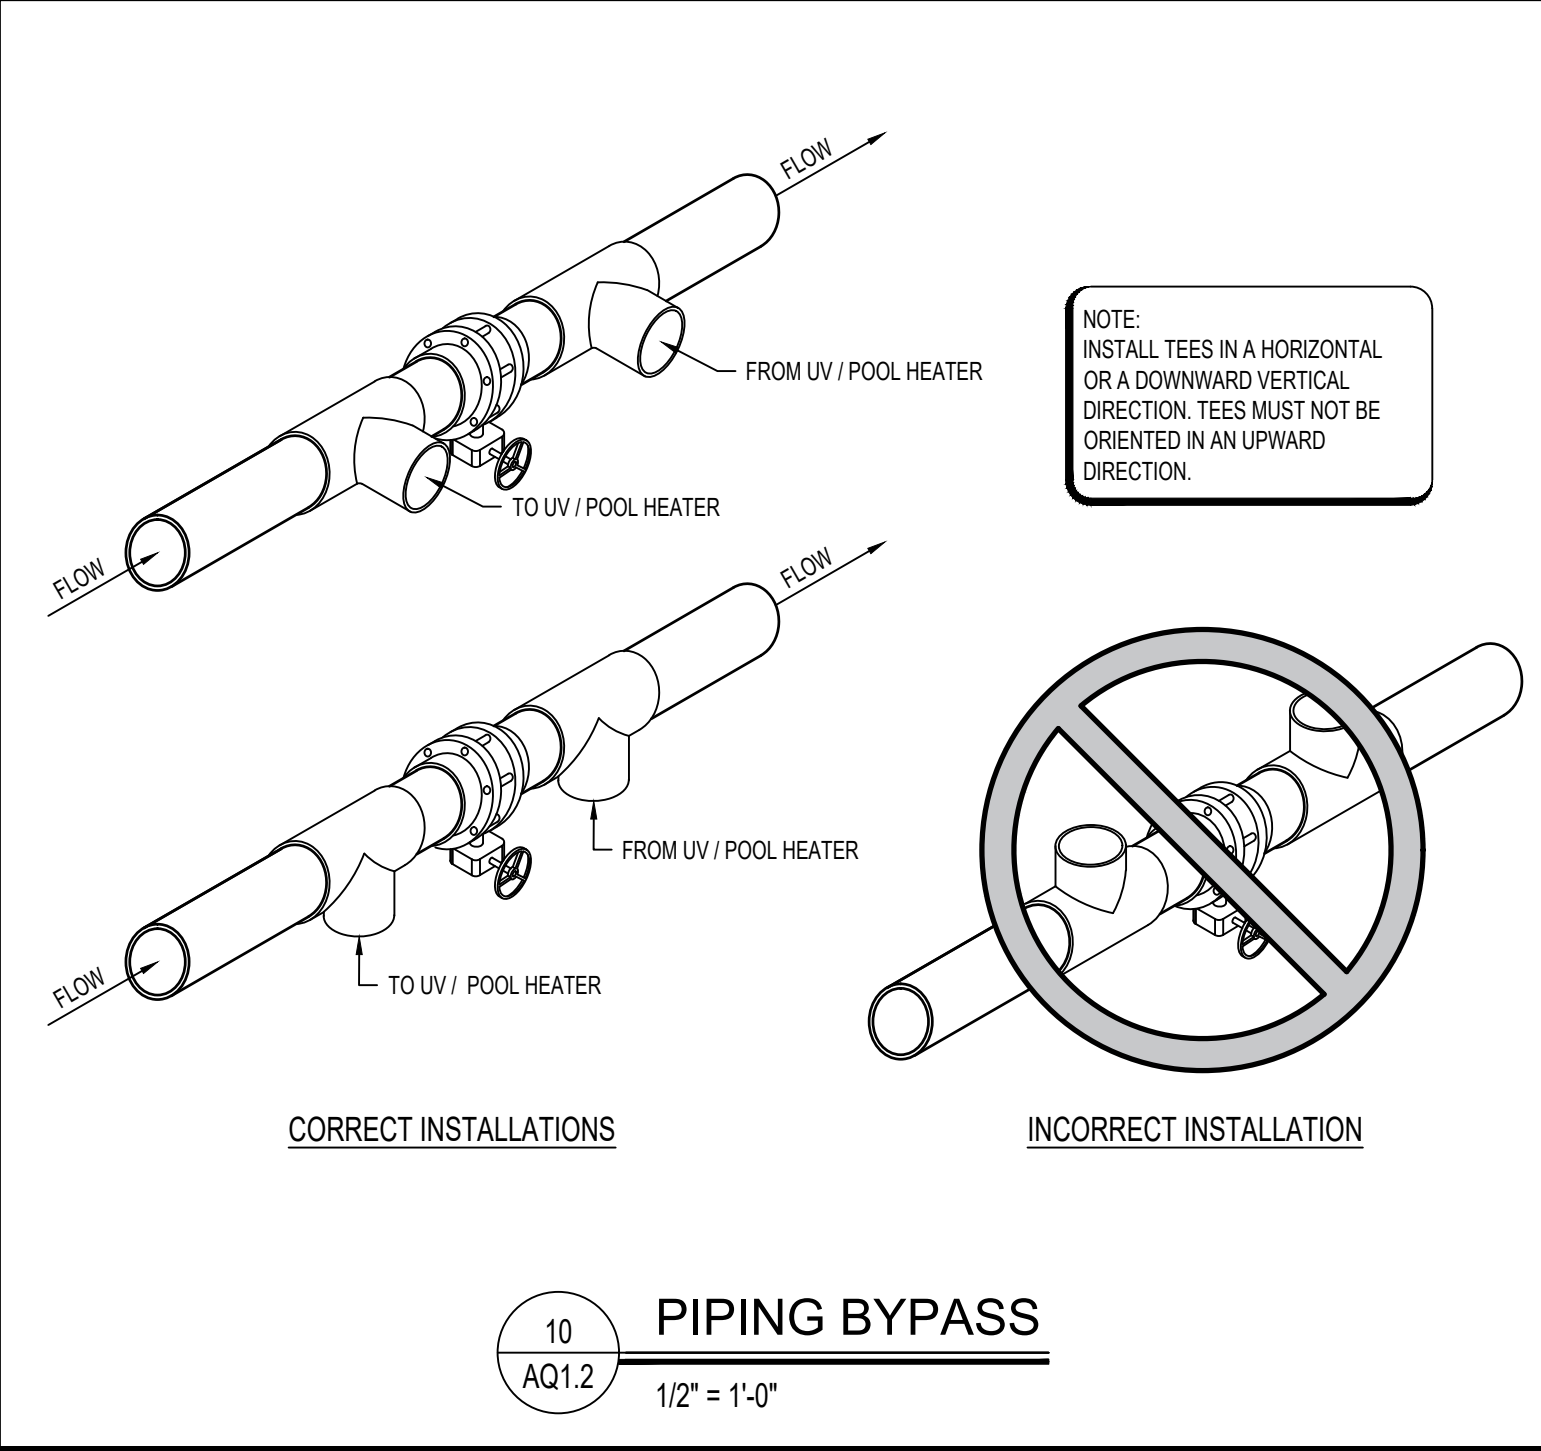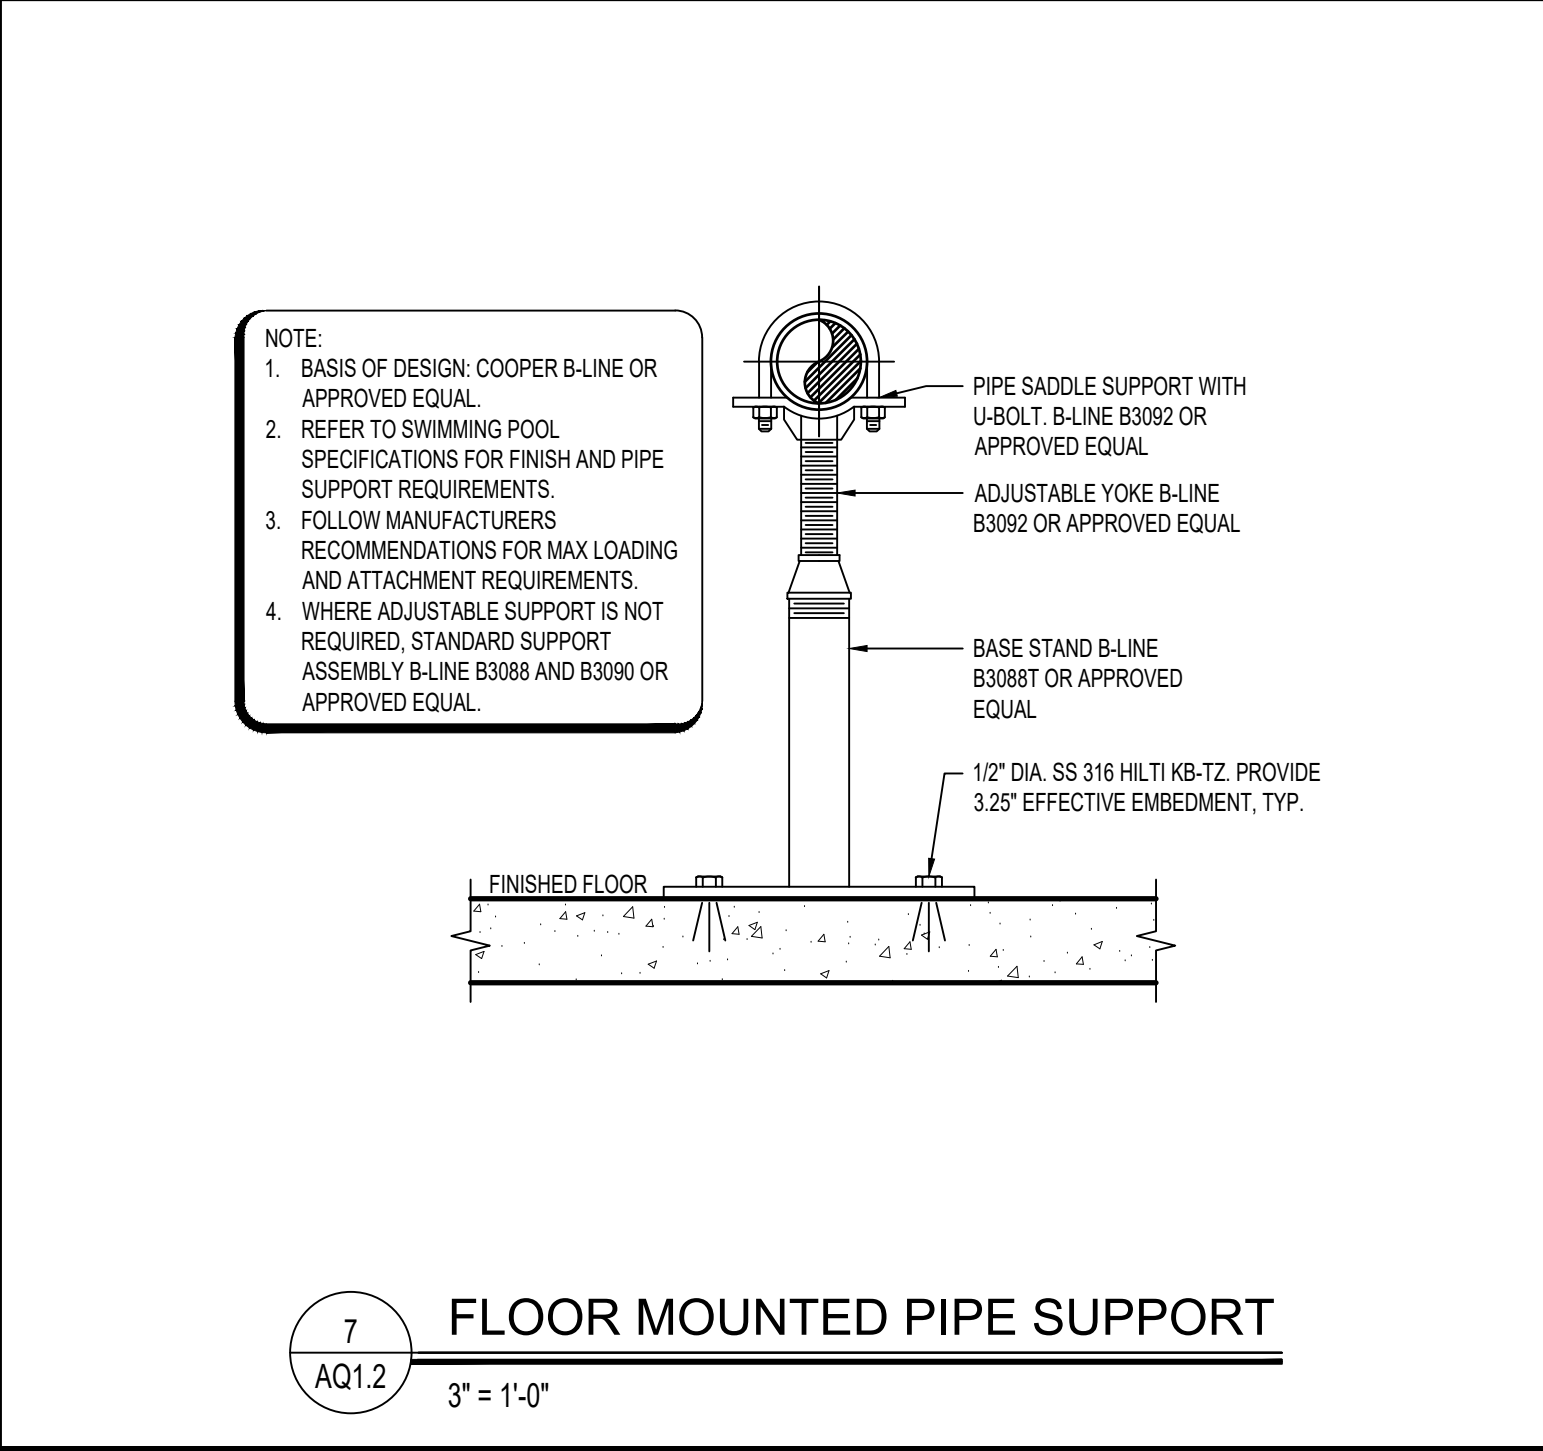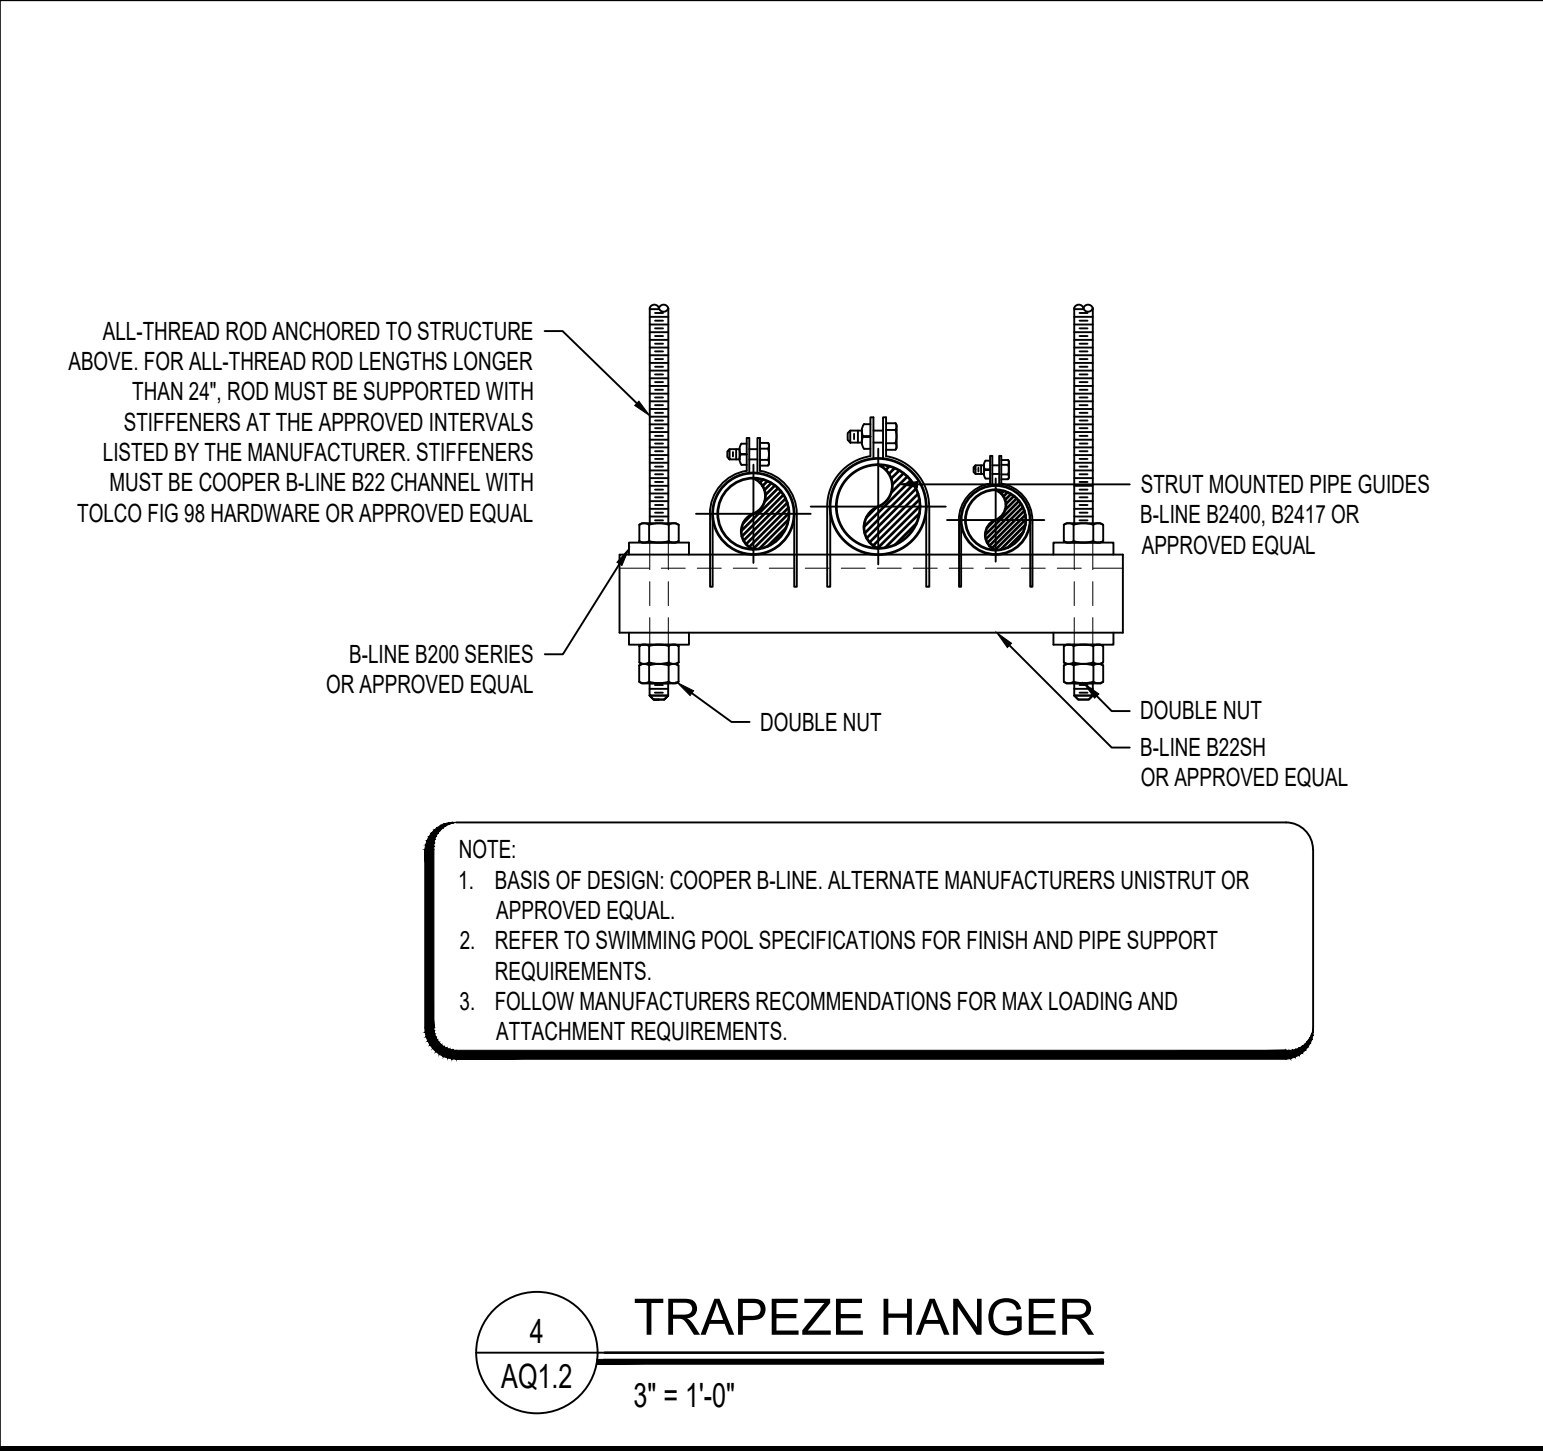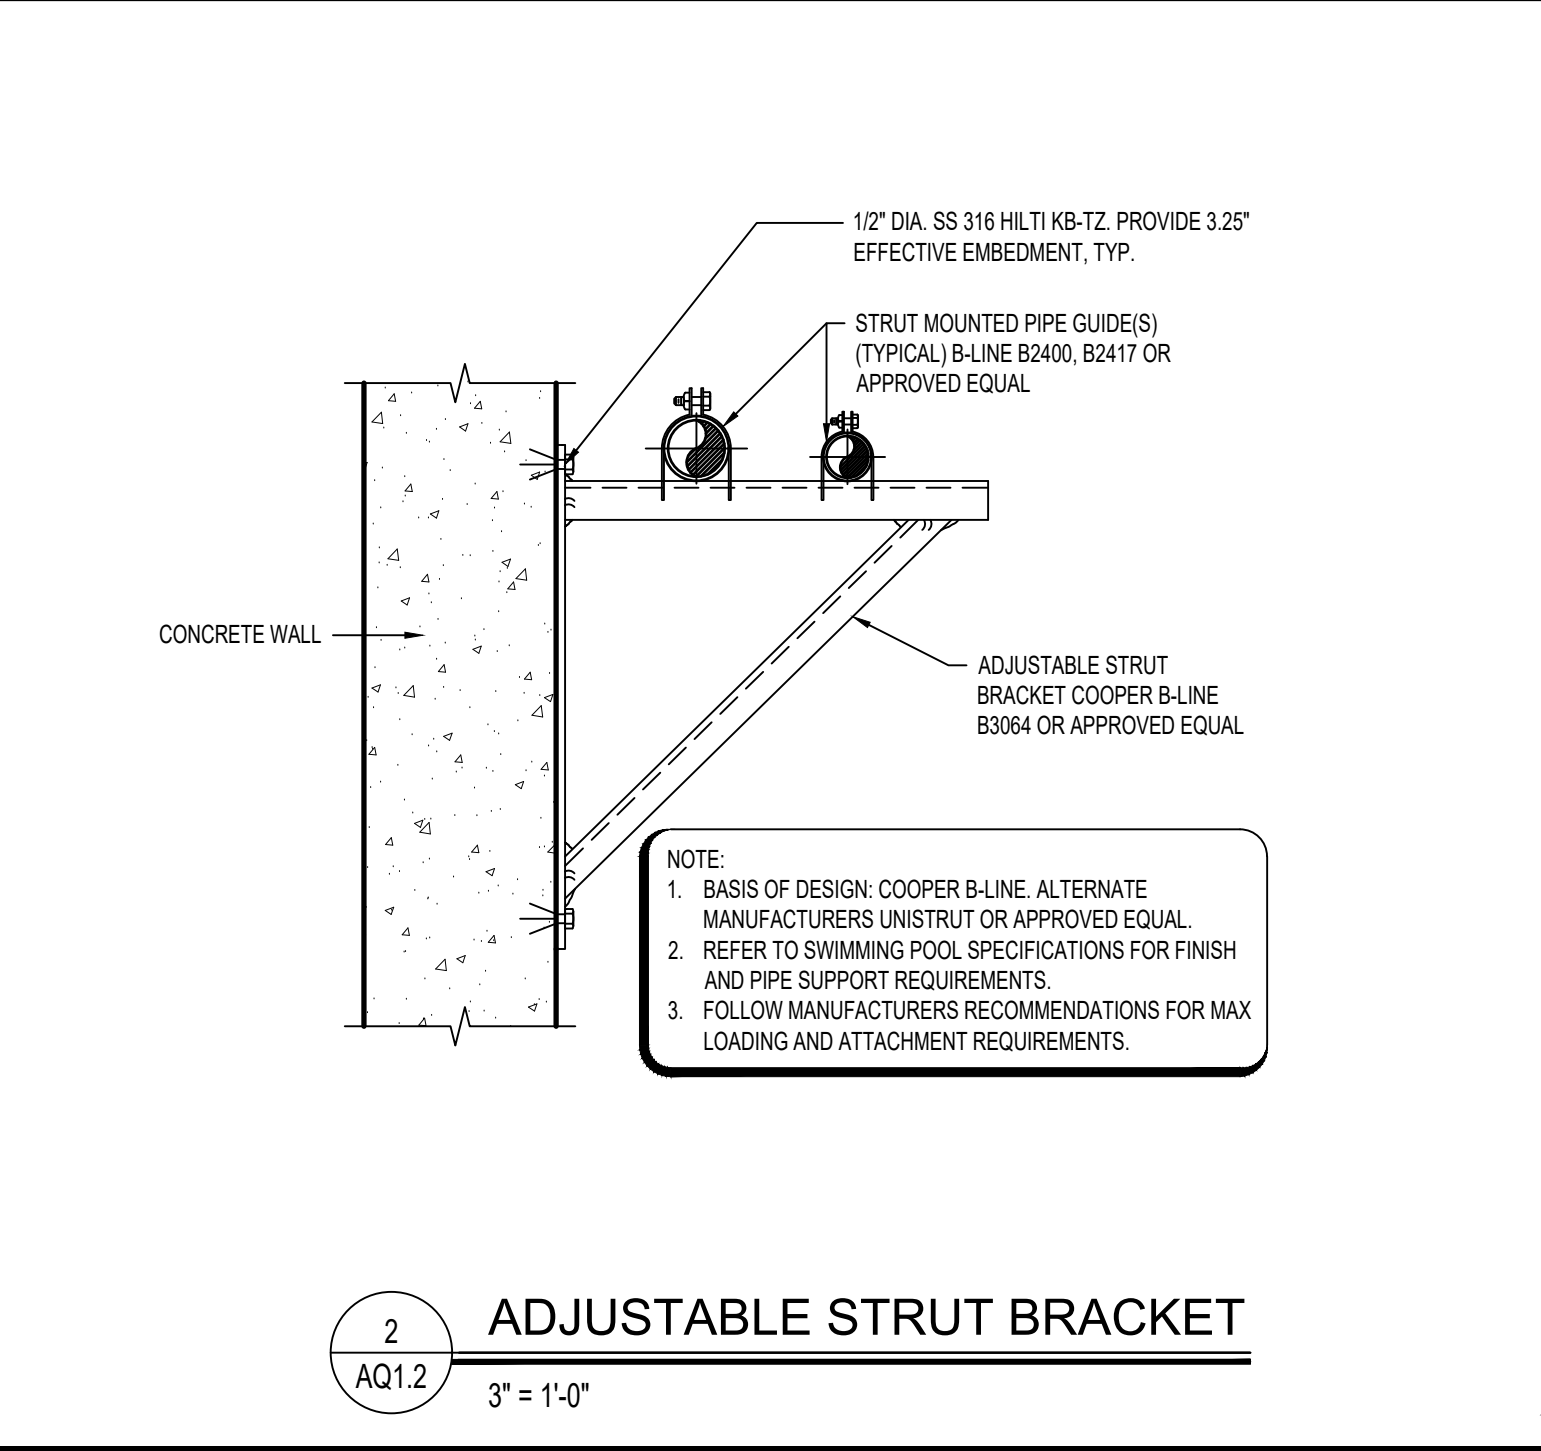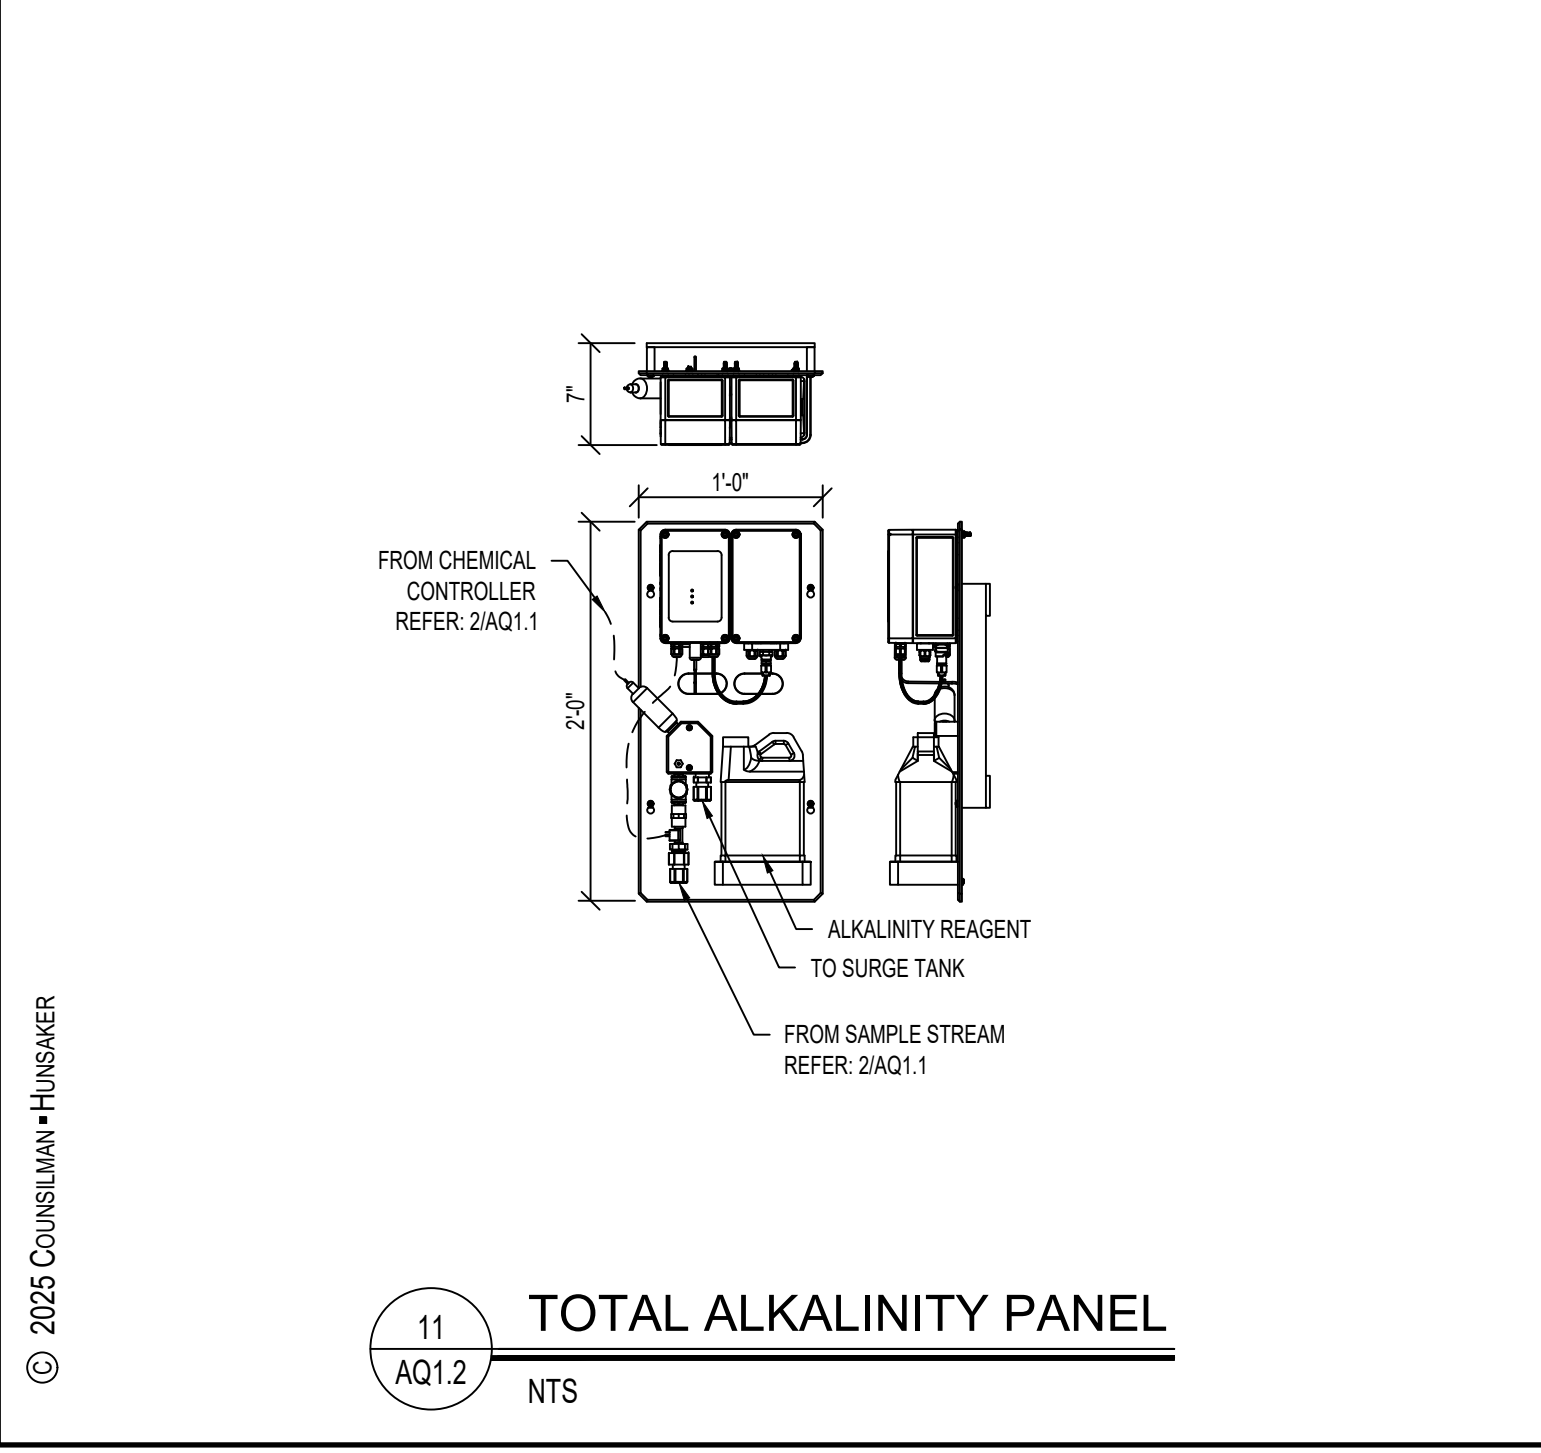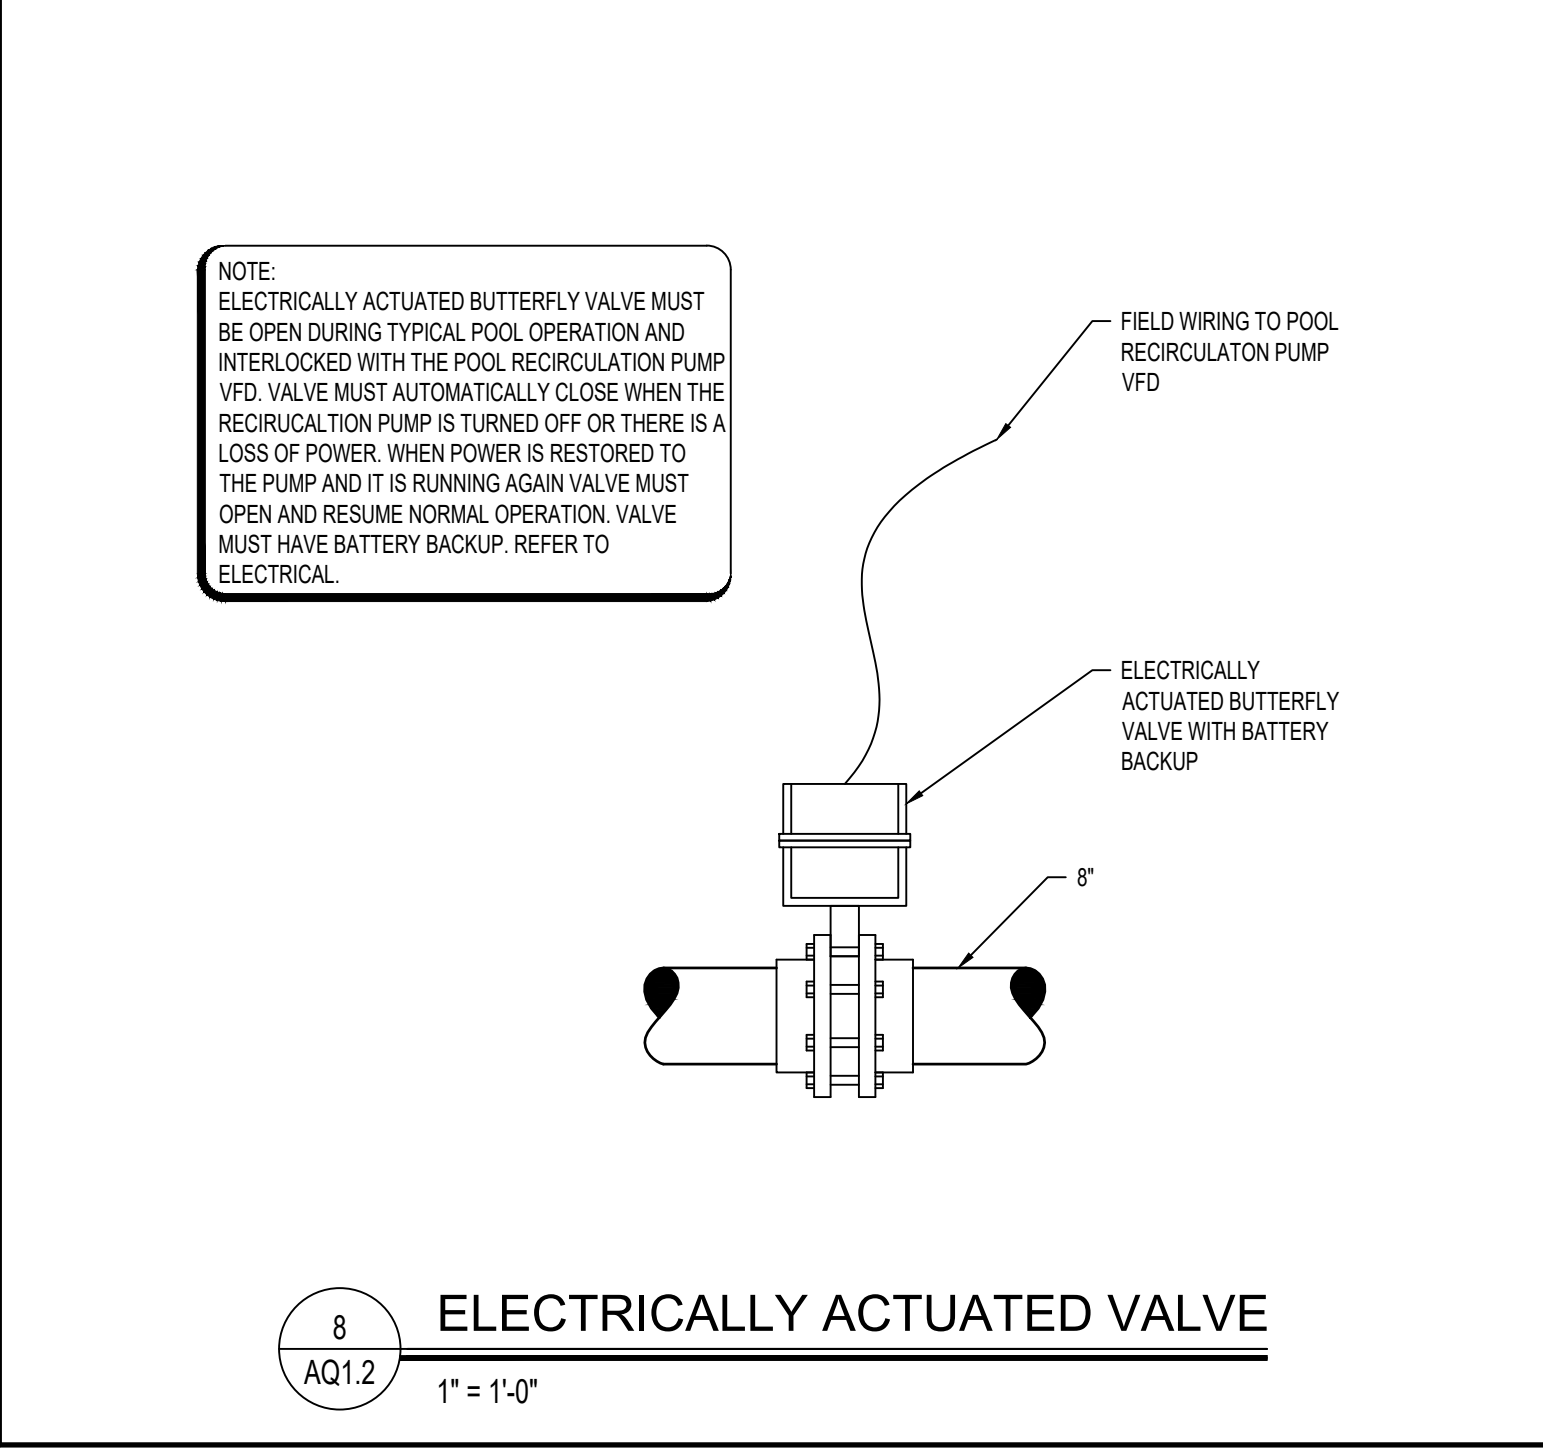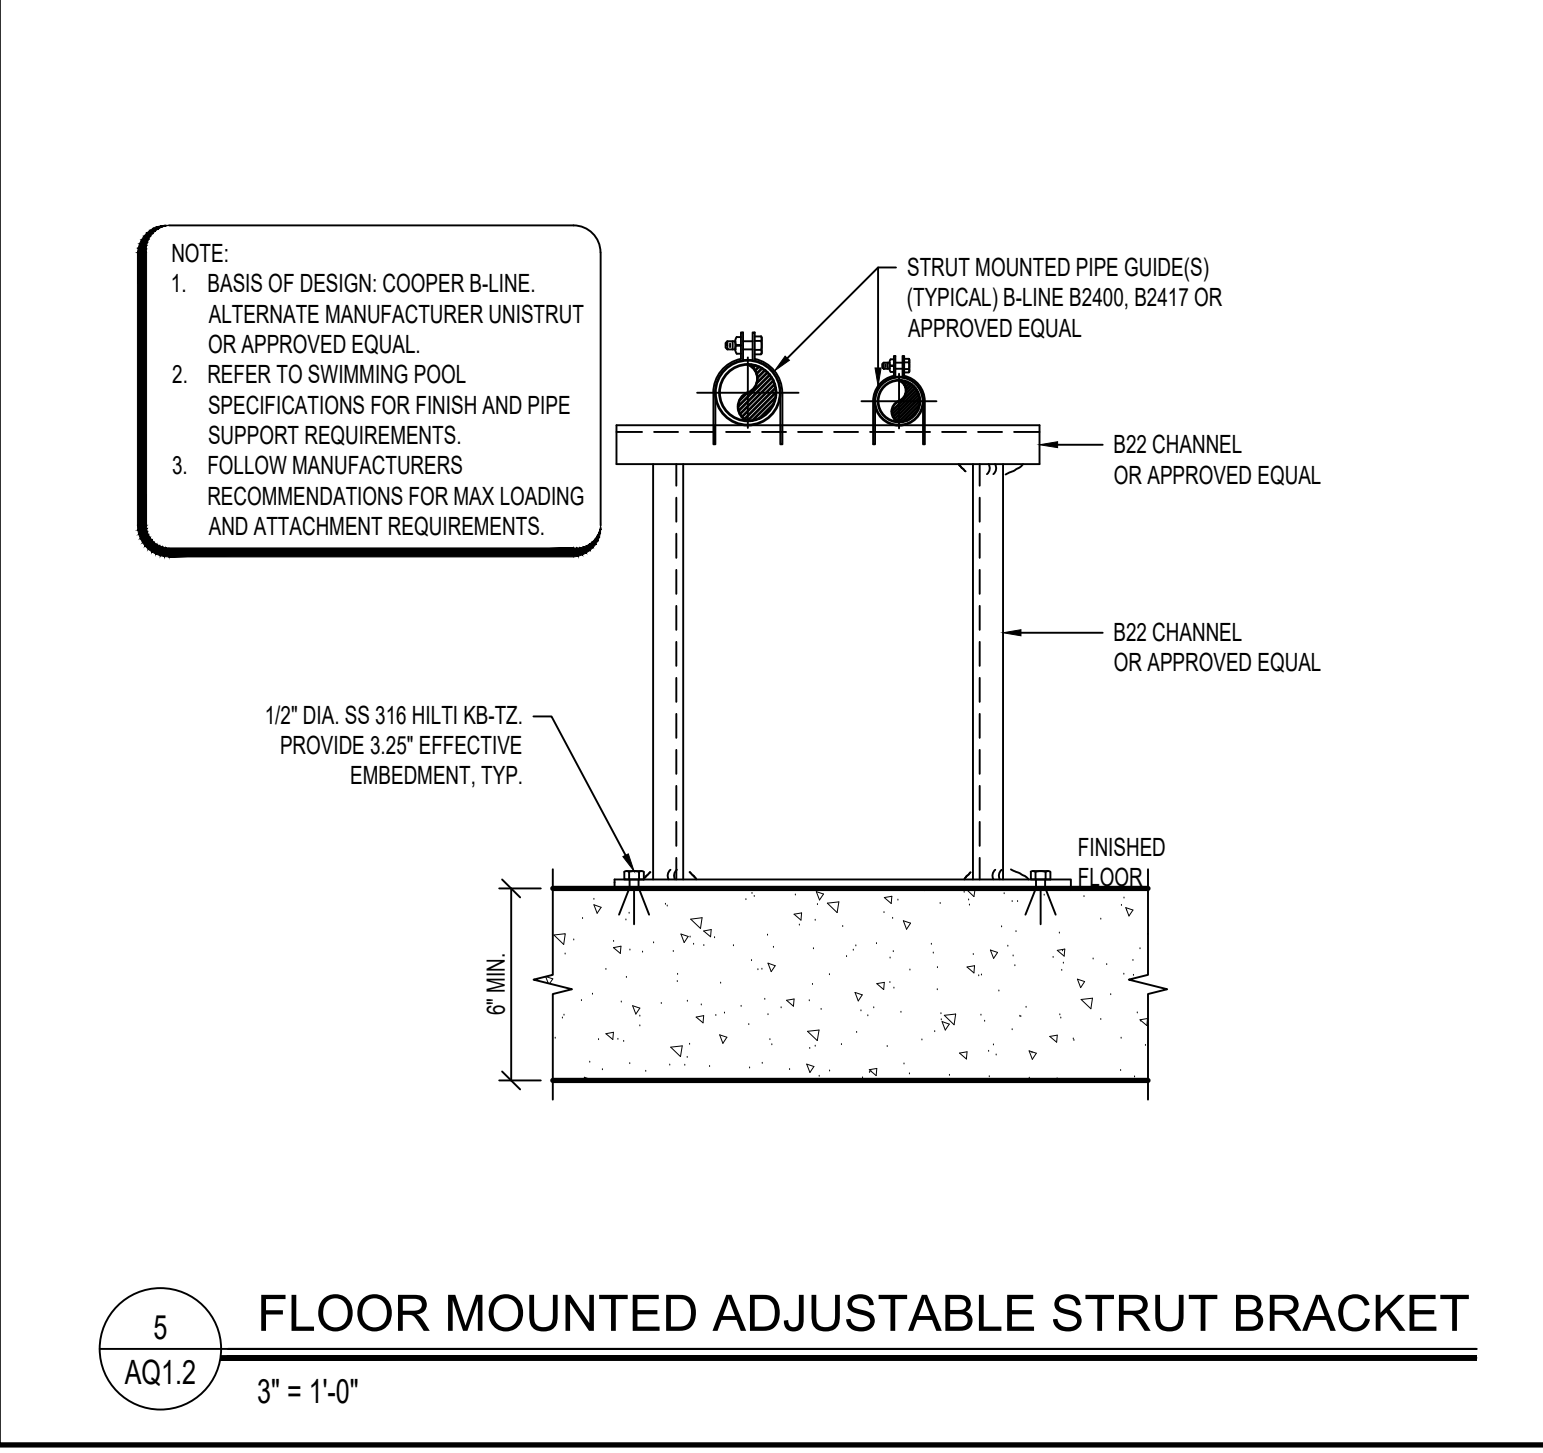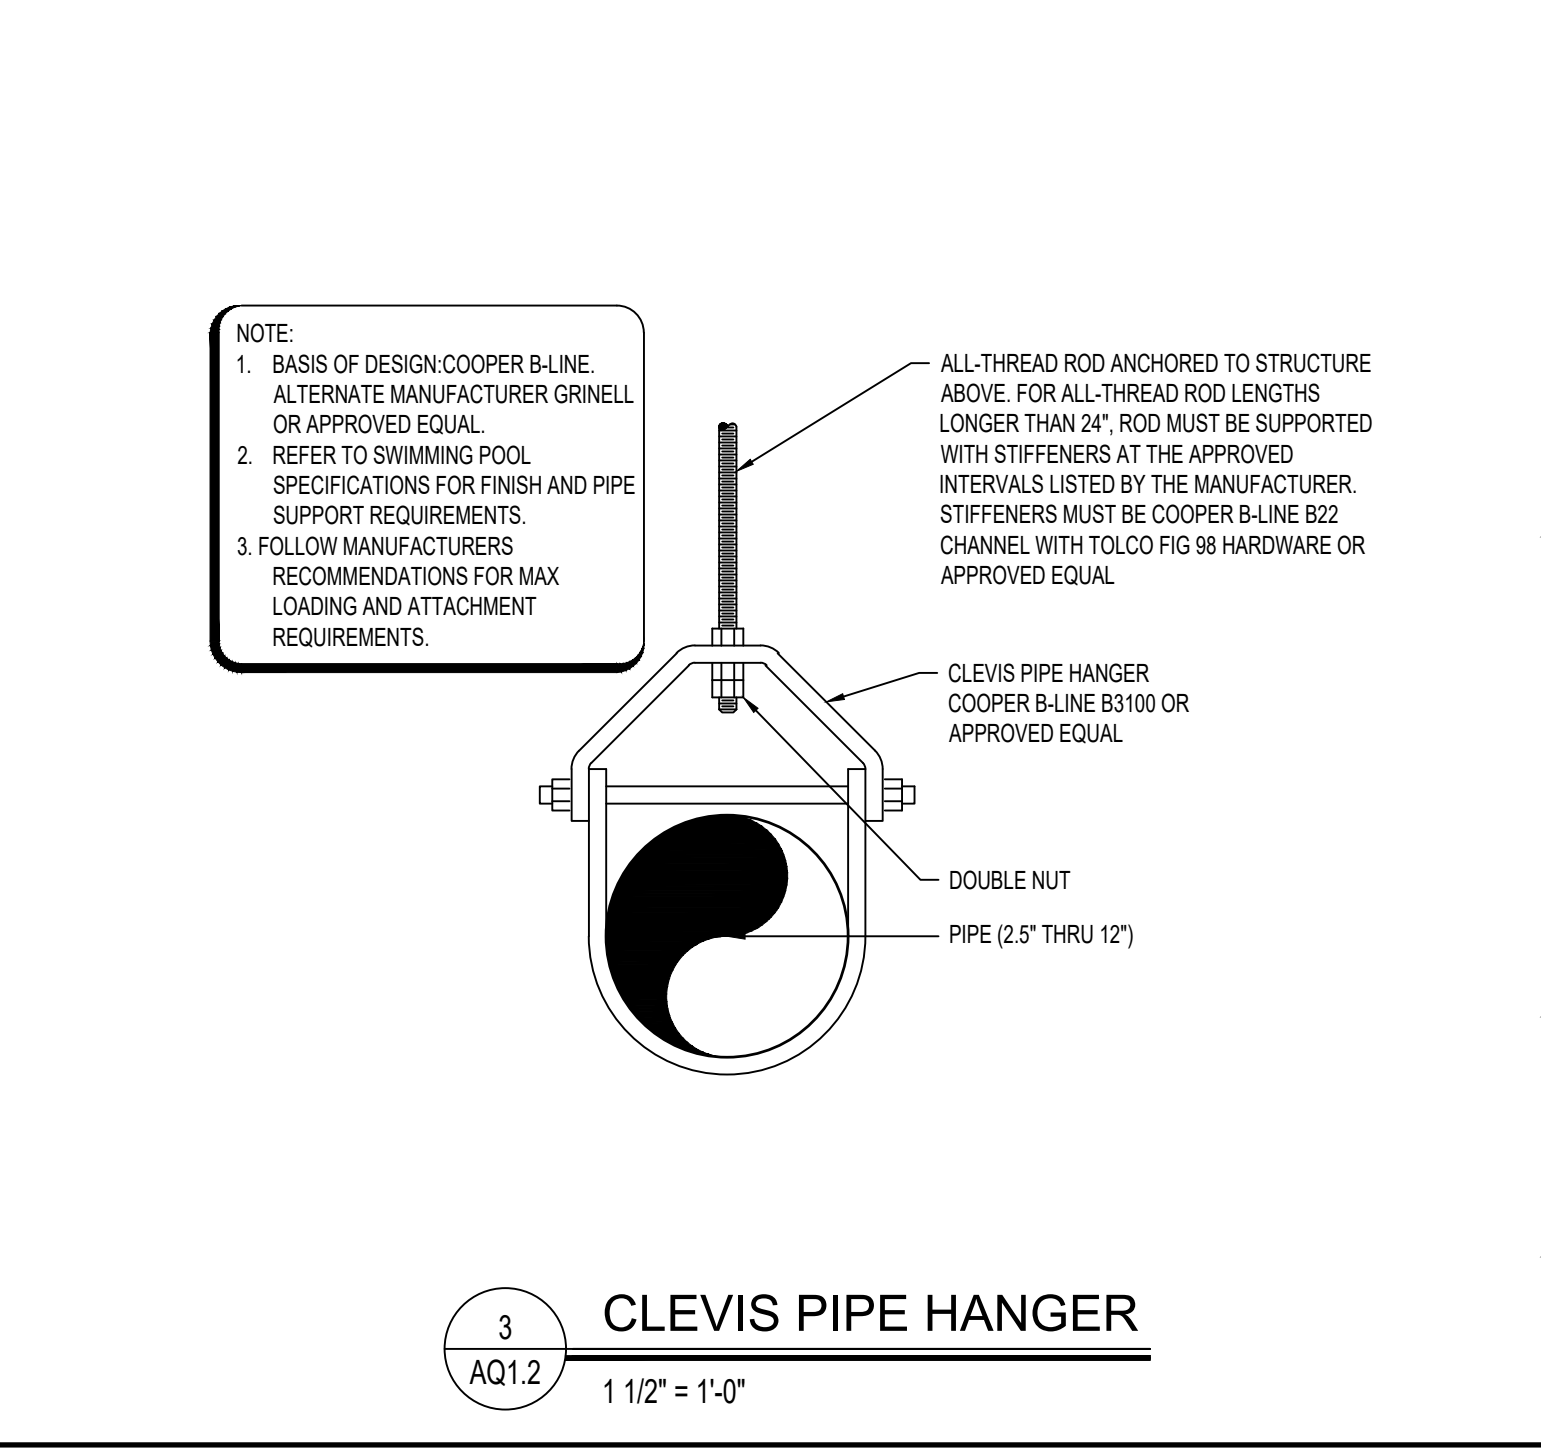

ABBREV.	DESCRIPTION
AAV	AUTOMATIC AIR VENT / AIR ADMITTANCE VALVE
AD	ACCESS DOOR
AE	AIR EXTRACTOR
AFF	ABOVE FINISHED FLOOR
APD	AIR PRESSURE DROP
ASR	AUTOMATIC SPRINKLER RISER
BFP	BACKFLOW PREVENTER
BHP	BRAKE HORSEPOWER
BOD	BOTTOM OF DUCT
BTU	BRITISH THERMAL UNIT
BTUH	BRITISH THERMAL UNITS PER HOUR
BWV	BACKWATER VALVE
CAP	CAPACITY
CAV	CONSTANT AIR VOLUME
CFH	CUBIC FEET PER HOUR
CFM	CUBIC FEET PER MINUTE
CIRC	CIRCULATING
CLG	COOLING
CO	CLEAN OUT
CONT	CONTINUATION OR CONTINUED
CONV	CONNECTOR
CUH	CABINET UNIT HEATER
CV	CONTROL VALVE
DB	DRY BULB TEMPERATURE
DEG	DEGREES
DDC	DIRECT DIGITAL CONTROL
DN	DOWN
DTC	DRAIN TILE CONNECTION
DWH	DOMESTIC WATER HEATER
(E)	EXISTING
EA/EXH	EXHAUST AIR
EAT	ENTERING AIR TEMPERATURE
EDB	ENTERING DRY BULB TEMPERATURE
EF	EXHAUST FAN
EJ	EXPANSION JOINT
EL	ELEVATION
ELECT	ELECTRICAL
EMS	ENERGY MANAGEMENT SYSTEM
ESP	EXTERNAL STATIC PRESSURE
EWB	ENTERING WET BULB TEMPERATURE
EWC	ELECTRIC WATER COOLER
°F	DEGREES FAHRENHEIT
FA	FACE AREA (COIL) / FREE AREA (LOUVER)
FC	FLEXIBLE CONNECTION
FD	FLOOR DRAIN
FDC	FIRE DEPARTMENT CONNECTION
FH	FIRE HYDRANT
FHC	FIRE HOSE CABINET
FHR	FIRE HOSE RACK
FHV	FIRE HOSE VALVE
FLA	FULL LOAD AMPS
FLR	FLOOR
PPM	FEET PER MINUTE
FFD	FUNNEL FLOOR DRAIN
FFE	FINISHED FLOOR ELEVATION
FS	FLOOR SINK
FT	FEET
FURN	FURNISHED
FV	FACE VELOCITY
FVC	FIRE VALVE CABINET
GAL	GALLON
GPH	GALLONS PER HOUR
GPM	GALLONS PER MINUTE
HB	HOSE BIBB
HO	HUB OUTLET
HP	HORSEPOWER

ABBREV.	DESCRIPTION
HR	HOUR
HTG	HEATING
HYD	HYDRANT
HZ	HERTZ
ID	INSIDE DIAMETER
IE	INVERT ELEVATION
IN	INCHES
INST	INSTALLED
INV	INVERT
ISP	INTERNAL STATIC PRESSURE
IW	INDIRECT WASTE
KW	KILOWATT
LAT	LEAVING AIR TEMPERATURE
LAV	LAVATORY
BS/HR	POUNDS PER HOUR
LDB	LEAVING DRY BULB TEMPERATURE
LRA	LOCKED ROTOR AMPS
LWB	LEAVING WET BULB TEMPERATURE
MAV	MANUAL AIR VENT
MAX	MAXIMUM
MBH	1000 BRITISH THERMAL UNITS PER HOUR
MCA	MINIMUM CIRCUIT AMPACITY
MECH	MECHANICAL
MFR	MANUFACTURER
MH	MANHOLE
MIN	MINIMUM
MISC	MISCELLANEOUS
MOD	MOTOR OPERATED DAMPER (AUTOMATIC)
MOP	MAXIMUM OVER-CURRENT PROTECTION
N.C.	NOISE CRITERIA
NIC	NOT IN CONTRACT
NC	NORMALLY CLOSED
NO	NORMALLY OPEN
NOM	NOMINAL
OA	OUTSIDE AIR
OBD	OPOSED BLADE DAMPER
OC	ON CENTER / CENTER TO CENTER
OD	OUTSIDE DIAMETER
OED	OPEN ENDED DUCT
ORS	OVERFLOW ROOF SUMP
OS&Y	OUTSIDE SCREW AND YOKE
PD	PRESSURE DROP (FEET OF WATER)
PRV	PRESSURE REDUCING VALVE
PSIA	POUNDS PER SQUARE INCH - ABSOLUTE
PSIG	POUNDS PER SQUARE INCH - GAUGE
PT	PRESSURE / TEMPERATURE PORT
RA	RETURN AIR
RH	RELATIVE HUMIDITY
REQD	REQUIRED
REL.A	RELIEF AIR
RPM	REVOLUTIONS PER MINUTE
RPZ	REDUCED PRESSURE ZONE
RS	ROOF SUMP
SA	SUPPLY AIR
SH	SHOWER
SP	STATIC PRESSURE
SF / SF	SQUARE FOOT/SQUARE FEET
SS	SERVICE SINK
TC	TEMPERATURE CONTROL
T & P	TEMPERATURE AND PRESSURE
TSP	TOTAL STATIC PRESSURE
TYP	TYPICAL
UG	UNDERGROUND
UH	UNIT HEATER
UL	UNDERWRITERS LABORATORY
UNO	UNLESS NOTED OTHERWISE

ABBREV.	DESCRIPTION
UR	URINAL
VD	VOLUME DAMPER (MANUALLY ADJUSTABLE)
VTR	VENT THRU ROOF
W	WASTE
W&V	WASTE AND VENT
WB	WET BULB TEMPERATURE
WC	WATER CLOSET
WG	WATER GAUGE
WH	WALL HYDRANT

MECHANICAL PIPING SYMBOLS

ABBREV.	DESCRIPTION
	PIPE ELBOW UP
	PIPE ELBOW DOWN
	PIPE TEE DOWN
	DIRECTION OF FLOW
	UNION
	STRAINER
	CONCENTRIC REDUCER
	ECCENTRIC REDUCER
	EXPANSION JOINT
	FLEXIBLE CONNECTION
	PIPE ANCHOR
	PIPE GUIDE
	PIPE CAP OR PLUG
	ISOLATION VALVE
	CIRCULATING PUMP
	GLOBE VALVE
	BALL VALVE
	BUTTERFLY VALVE
	ANGLE VALVE
	CHECK VALVE (SWING)
	CHECK VALVE (SPRING)
	PLUG VALVE
	NEEDLE VALVE
	OUTSIDE SCREW AND YOKE VALVE (OS&Y)
	PRESSURE REGULATING VALVE
	SOLENOID VALVE
	CONTROL VALVE (2-WAY / 3-WAY)
	CENTRIFUGAL FAN
	AUTOMATIC GAS SHUT-OFF VALVE
	TRAP (PLAN VIEW)
	FLOOR DRAIN / FUNNEL FLOOR DRAIN (PLAN VIEW)
	FLOOR DRAIN / FUNNEL FLOOR DRAIN (ELEVATION VIEW)
	ROOF SUMP
	CLEAN OUT (IN FLOOR)
	CLEAN OUT (IN LINE)
	CLEAN OUT (WALL)
	BACKFLOW PREVENTER
	WATER METER ASSEMBLY
	HOSE BIBB, WALL HYDRANT
	DIRECTION OF PIPE PITCH
	SPRINKLER HEAD (UPRIGHT)
	SPRINKLER HEAD (SIDEWALL)
	FLOW SWITCH
	SIAMESE CONNECTION (YARD)
	SIAMESE CONNECTION (WALL MOUNTED)
	FIRE HYDRANT
	FLOW MEASURING DEVICE
	BALANCING VALVE
	COMBINATION FLOW MEASURING AND BALANCING DEVICE
	AUTOMATIC AIR VALVE
	MANUAL AIR VALVE

	DESCRIPTION
	RECTANGULAR TAKE-OFF (SINGLE LINE)
	RECTANGULAR TAKE-OFF (DOUBLE LINE)
	ROUND TAKE-OFF (SINGLE LINE)
	ROUND TAKE-OFF (DOUBLE LINE)
	SPIN-IN FITTING (WITH VOLUME DAMPER)
	ELBOW (WITH TURNING VANES)
	RADIUS RECTANGULAR ELBOW
	RADIUS ROUND ELBOW
	RECTANGULAR ELBOW UP
	ROUND ELBOW UP
	RECTANGULAR ELBOW DOWN
	ROUND ELBOW DOWN
	CONCENTRIC TRANSITION (DOUBLE LINE)
	CONCENTRIC TRANSITION (SINGLE LINE)
	ECCENTRIC TRANSITION (DOUBLE LINE)
	ECCENTRIC TRANSITION (SINGLE LINE)
	INCLINED RISE IN DIRECTION OF AIR FLOW (DOUBLE LINE)
	INCLINED RISE IN DIRECTION OF AIR FLOW (SINGLE LINE)
	INCLINED DROP IN DIRECTION OF AIR FLOW (DOUBLE LINE)
	INCLINED DROP IN DIRECTION OF AIR FLOW (SINGLE LINE)
	FLEXIBLE CONNECTION
	FLEXIBLE DUCT CONNECTION TO SUPPLY DIFFUSER
	SUPPLY DIFFUSER
	LINEAR SLOT DIFFUSER
	RETURN OR EXHAUST GRILLE
	TRANSFER GRILLE
	CROSS SECTION OF SUPPLY AIR DUCT
	CROSS SECTION OF EXHAUST OR RETURN AIR DUCT
EXISTING	FIRE DAMPER (HORIZONTAL)
NEW	
EXISTING	FIRE DAMPER (VERTICAL)
NEW	
EXISTING	SMOKE DAMPER
NEW	
EXISTING	COMBINATION FIRE/SMOKE DAMPER (VERTICAL)
NEW	
EXISTING	COMBINATION FIRE/SMOKE DAMPER (HORIZONTAL)
NEW	
	VOLUME DAMPER (MANUALLY ADJUSTABLE)
	MOTORIZED DAMPER
	SMOKE DETECTOR
	CO2 SENSOR
	THERMOSTAT OR TEMPERATURE SENSOR
	HUMIDISTAT OR HUMIDITY SENSOR
	RETURN OR EXHAUST / SUPPLY AIR FLOW


	DESCRIPTION
1	COMPRESSED AIR PIPING
2	CONDENSATE DRAIN PIPING
3	RAIN TILE
4	FIRE PROTECTION PIPING
5	FUEL OIL RETURN PIPING
6	FUEL OIL SUPPLY PIPING
7	NATURAL GAS PIPING
8	BOOSTED-DOMESTIC COLD WATER PIPING
9	BOOSTED-DOMESTIC HOT WATER PIPING
10	BOOSTED COLD WATER PIPING
11	DRINKABLE POTABLE COLD WATER PIPING
12	TEMPERED WATER PIPING
13	DOMESTIC HOT WATER PIPING
14	DOMESTIC 140°F HOT WATER PIPING
15	DOMESTIC HOT WATER RETURN PIPING
16	SANITARY WASTE PIPING
17	DUMPED SANITARY PIPING
18	VENT PIPING
19	STORM SEWER PIPING
20	DUMPED STORM PIPING
21	INDUSTRIAL PIPING
22	OVERFLOW RAIN CONDUCTOR PIPING
23	CILLED WATER RETURN PIPING
24	CILLED WATER SUPPLY PIPING
25	CONDENSER WATER RETURN PIPING
26	CONDENSER WATER SUPPLY PIPING
27	EATING HOT WATER RETURN PIPING
28	EATING HOT WATER SUPPLY PIPING
29	EAT PUMP LOOP RETURN PIPING
30	EAT PUMP LOOP SUPPLY PIPING
31	REFRIGERANT LIQUID PIPING
32	REFRIGERANT SUCTION PIPING
33	OT GAS BY-PASS PIPING
34	EO HEAT EXCHANGE RETURN
35	EO HEAT EXCHANGE SUPPLY
36	STEAM PIPING
37	HIGH PRESSURE STEAM PIPING
38	LOW PRESSURE STEAM PIPING
39	STEAM CONDENSATE RETURN PIPING
40	DUMPED STEAM CONDENSATE RETURN PIPING
41	LOW PRESSURE CONDENSATE PIPING
42	HIGH PRESSURE CONDENSATE PIPING
43	MEDICAL AIR PIPING
44	NITROGEN GAS PIPING
45	OXYGEN GAS PIPING
46	VACUUM PIPING

SHT NO	DESCRIPTION
M0.00	MECHANICAL GENERAL INFORMATION
PD2.10K	PLUMBING LOWER LEVEL DEMOLITION PLAN - UNIT K
P2.10K	PLUMBING LOWER LEVEL NEW WORK PLAN - UNIT K

SYMBOL	DESCRIPTION
	NEW WORK KEY NOTE NO. 1
	DEMOLITION KEY NOTE NO. 1
<u>AHU-1</u>	EQUIPMENT TAG
AIR TERMINAL TAG: S-1 12x12 100-2	S = SUPPLY R = RETURN E = EXHAUST T = TRANSFER
IE: DIFFUSER TYPE = S-1 NECK SIZE = 12x12 CFM = 150 (TYPICAL FOR 2)	
	EXISTING DEVICES OR EQUIPMENT
	NEW OR MODIFIED DEVICES OR EQUIPMENT
	EXISTING SYSTEM COMPONENT TO BE REMOVED
	POINT OF NEW CONNECTION

YEAR	CODE
2015	MICHIGAN BUILDING CODE
2015	MICHIGAN REHABILITATION CODE FOR EXISTING BUILDINGS
2021	MICHIGAN PLUMBING CODE
2021	MICHIGAN MECHANICAL CODE
2015	MICHIGAN UNIFORM ENERGY CODE
2015	INTERNATIONAL FUEL GAS CODE
2012	NFPA 101 WITH BFS AMENDMENTS

ISSUE DATE	ISSUED FOR
02/19/2025	BIDS
DRAWN	MPH
CHECKED	MPH
APPROVED	MPH

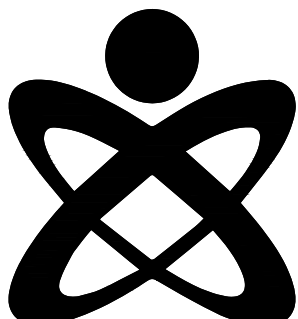

UNIFIED BUILDING
SYSTEMS ENGINEERING
69 S. GRATIOT AVE.
MT. CLEMENS, MI 48043
UBS PROJECT 029.24.17



FRENCH
2851 High Meadow Circle | Suite 100
Auburn Hills | MI 48326
248.656.1377

PROJECT

Livonia Public Schools Stevenson High School Pool Filtration Project

LIVONIA,
MICHIGAN

SHEET

MECHANICAL GENERAL INFORMATION

PROJECT NUMBER

2024-081


SHEET NUMBER

MO.00



SCALE: 1/8" = 1'-0"

DEMOLITION KEYED NOTES	
1	REMOVE POOL HEATING WATER SUPPLY AND RETURN PIPING TO POINT INDICATED. TEMPORARILY CAP PIPING AND PREPARE FOR NEW CONNECTION.

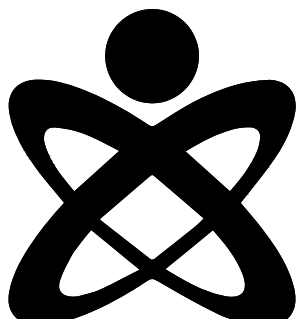

2851 High Meadow Circle | Suite 100
Auburn Hills | MI 48326
248.656.1377


Livonia Public Schools Stevenson High School Pool Filtration Project

SHEET

PROJECT NUMBER

SHEET NUMBER

PD2.10K

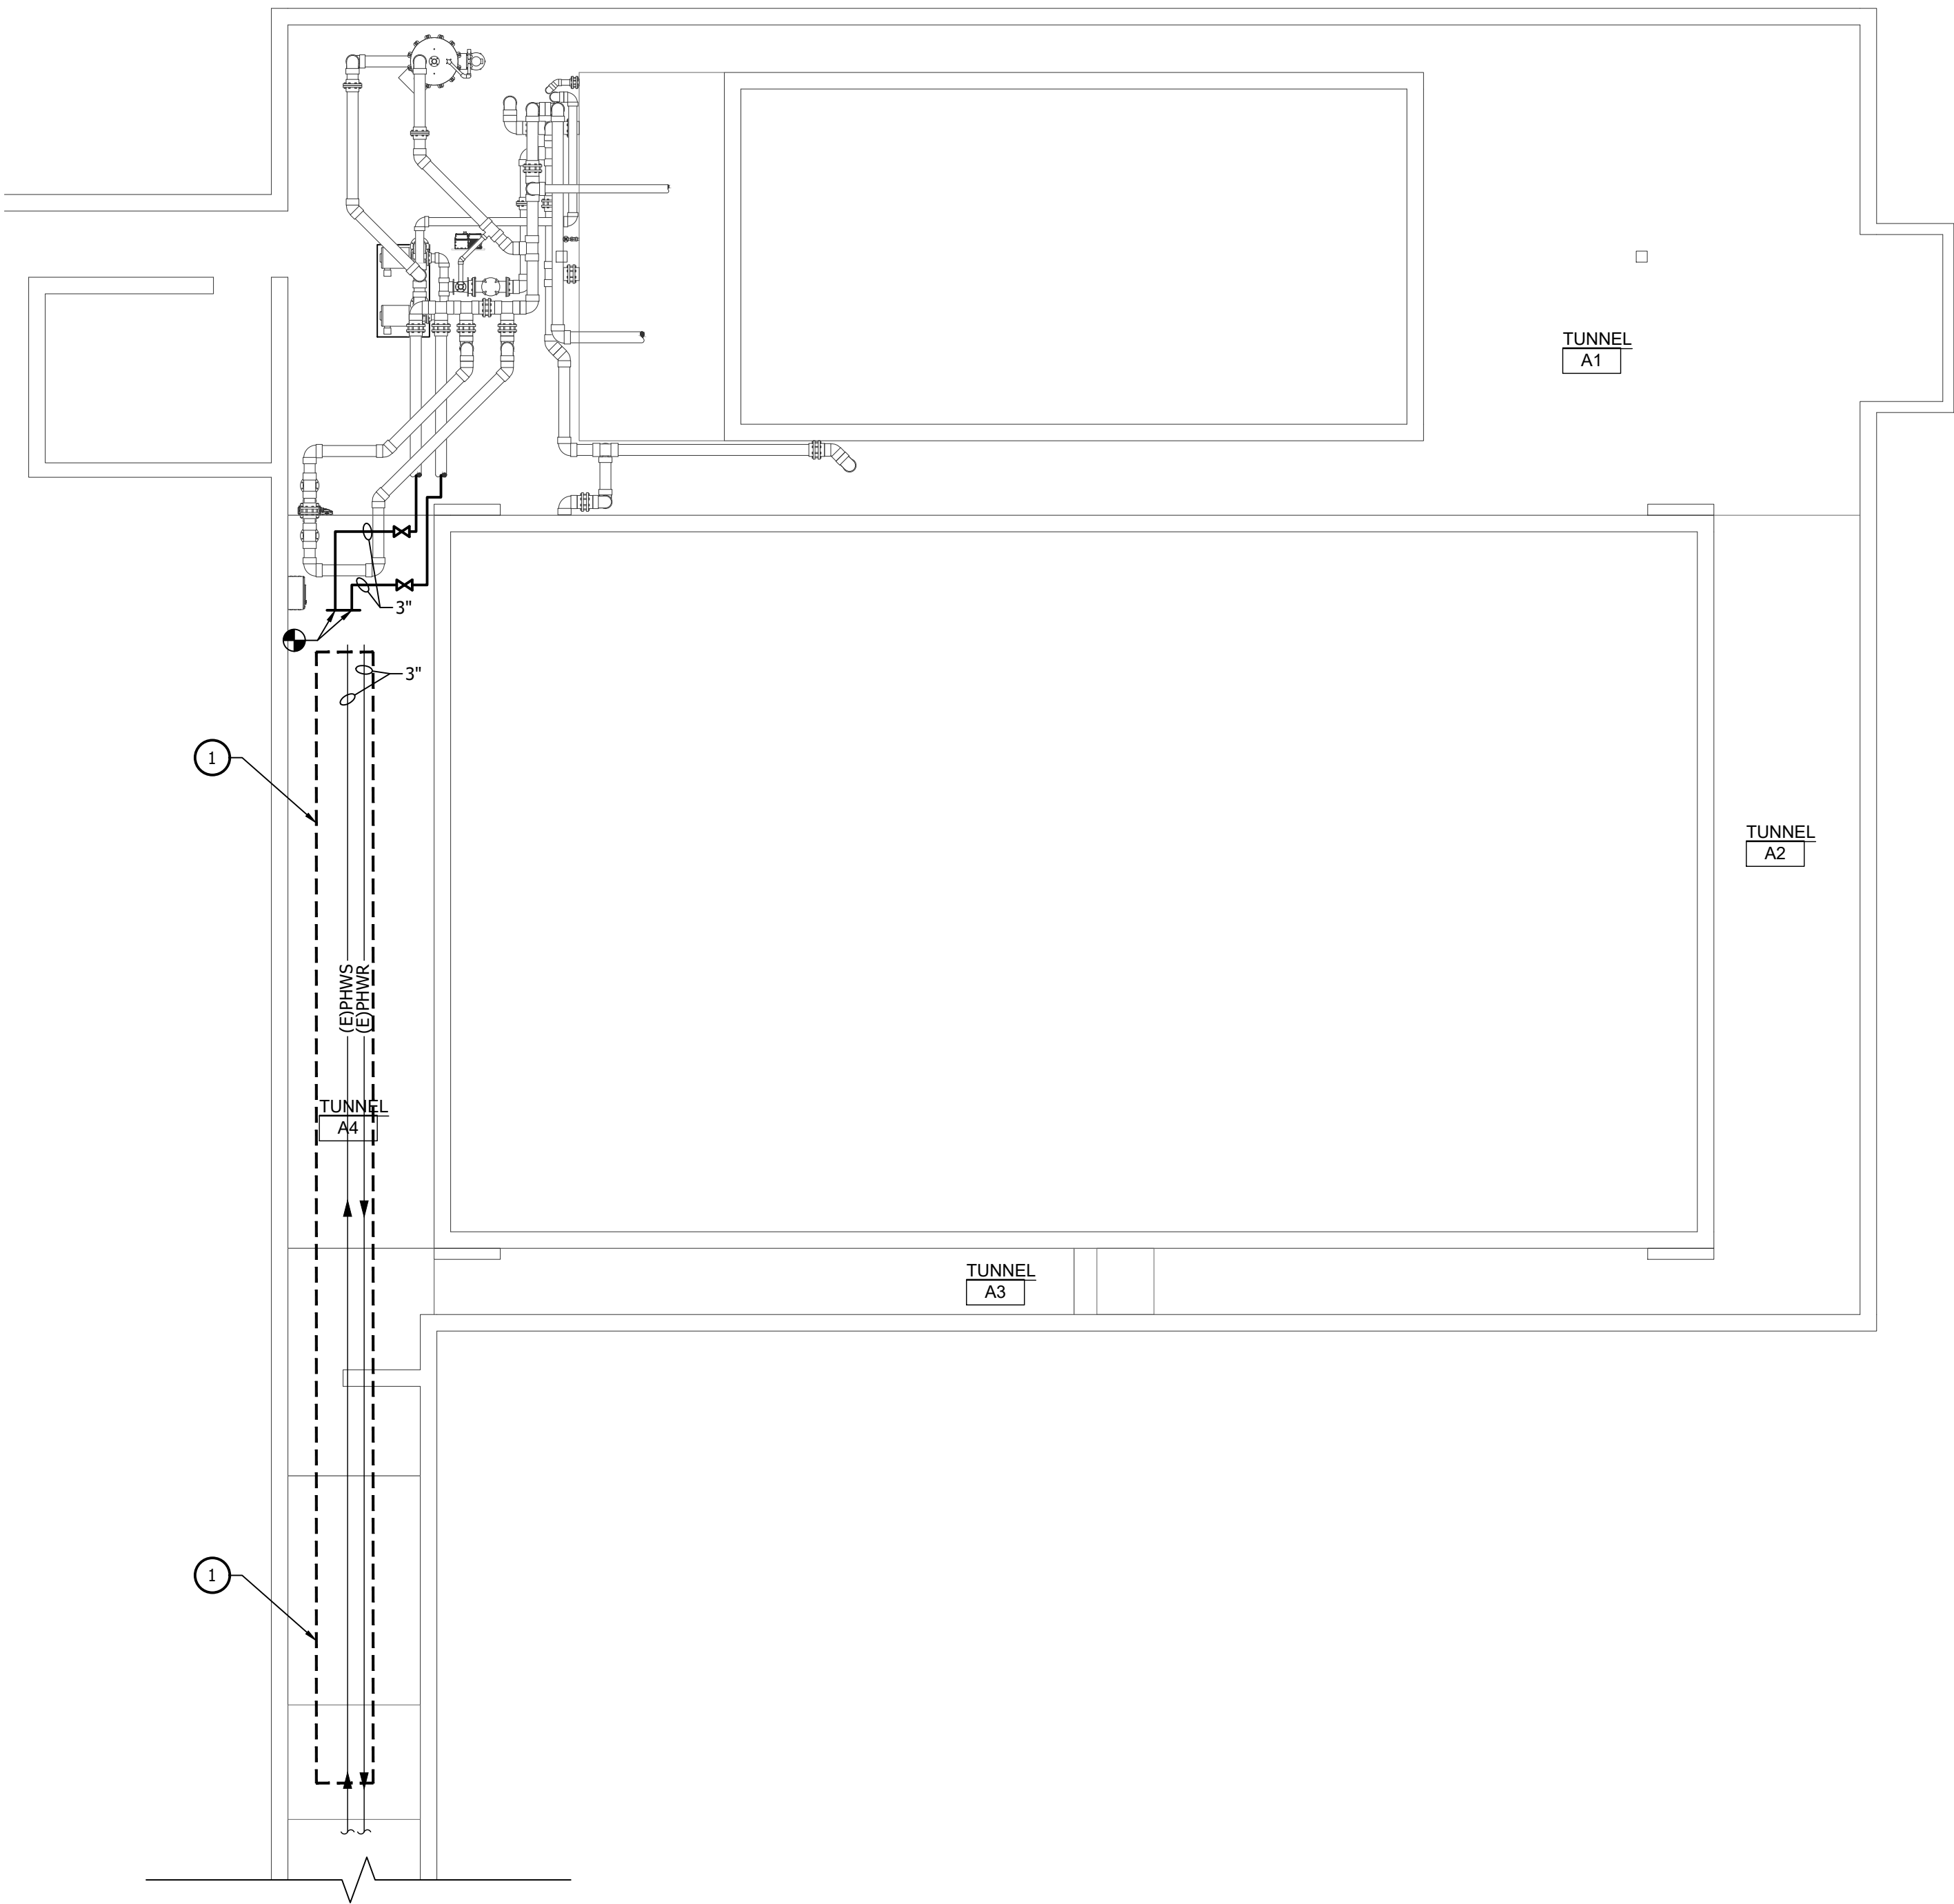

PLUMBING GENERAL NOTES	
A	THESE DRAWINGS ARE DIAGRAMMATIC AND INDICATE THE GENERAL EXTENT OF WORK TO BE PERFORMED. THE EXACT EXTENT OF DEMOLITION SHALL BE DETERMINED BY THE NEW WORK.
B	ANY INTERRUPTIONS OF EXISTING SERVICES AND/OR EQUIPMENT SHALL BE PERFORMED AT A TIME APPROVED IN ADVANCE BY OWNER'S REPRESENTATIVE SO AS NOT TO INTERFERE WITH THE PRESENT BUILDING'S OPERATION.
C	PRIOR TO COMMENCEMENT OF WORK, CONTRACTOR SHALL VISIT THE SITE AND BECOME FAMILIAR WITH EXISTING SITE CONDITIONS, SYSTEMS, AND UTILITIES. NOTIFY DESIGN PROFESSIONAL OF ANY INTERFERENCES OR DISCREPANCIES.
D	ALL ITEMS INDICATED WITH CROSS-HATCHING SHALL BE REMOVED COMPLETELY WITH ALL RELATED ITEMS INCLUDING HANGERS, SUPPORTS, INSULATION, CONTROLS, ETC. CAP ALL OPEN-ENDED PIPES AND DUCTS.
E	THE OWNER SHALL HAVE FIRST RIGHT OF REFUSAL ON ALL EQUIPMENT BEING REMOVED. ALL ITEMS REMOVED SHALL BE LEGALLY DISPOSED OF. GENERAL CONTRACTOR SHALL BE RESPONSIBLE FOR ALL EXISTING RELOCATED AND OWNER-PROVIDED EQUIPMENT.
F	VERIFY DEPTH, SIZE, LOCATIONS, AND CONDITIONS OF EXISTING UTILITIES IN THE FIELD, INCLUDING POINTS OF CONNECTION PRIOR TO STARTING WORK.
G	ALL ITEMS ON DEMOLITION PLAN SHALL BE CONSIDERED EXISTING UNLESS OTHERWISE NOTED. ALL WORK INDICATED ON PLANS HAS BEEN LOCATED PER EXISTING DRAWINGS AND/OR FIELD OBSERVATION AND REQUIRES FIELD VERIFICATION.
H	ALL EXISTING WORK TO REMAIN SHALL BE PROTECTED FROM DAMAGE. WHERE DUCT WORK PIPE INSULATION HAS BEEN DAMAGED DURING DEMOLITION, THE CONTRACTOR SHALL REPAIR INSULATION AS REQUIRED TO MATCH EXISTING.
J	INSTALL ALL SANITARY AND STORM PIPING 2 1/2" OR LESS AT 1/4" PER FOOT AND 3" AND LARGER PIPING AT 1/8" PER FOOT MINIMUM UNLESS NOTED OTHERWISE. MINIMUM UNDERGROUND PIPE SIZE SHALL BE 3".

NEW WORK KEYED NOTES	
1	PROVIDE ADDITIONAL HANGERS IN TUNNEL (QTY:15) TO RESOLVE SAGGING OF EXISTING POOL HEATING PIPING. PROVIDE ADDITIONAL AS NECESSARY.

KEY PLAN

ISSUE DATE

02/19/2025

ISSUED FOR

BIDS

DRAWN

MPH

CHECKED

MPH

APPROVED

MPH

UNIFIED BUILDING
SYSTEMS ENGINEERING
69 S. GRATIOT AVE.
MT. CLEMENS, MI 48043
UBS PROJECT 029.24.17

FRENCH
2851 High Meadow Circle | Suite 100
Auburn Hills | MI 48326
248.656.1377

PROJECT

Livonia Public Schools
Stevenson High School
Pool Filtration Project

LIVONIA,
MICHIGAN

SHEET

PLUMBING LOWER
LEVEL NEW WORK PLAN
- UNIT K

PROJECT NUMBER

2024-081

SHEET NUMBER

P2.10K




 
SCALE: 1/8" = 1'-0"

THE FUTURE OF THE FUTURE



SCALE: 1/8" = 1'-0"

KEY PLAN

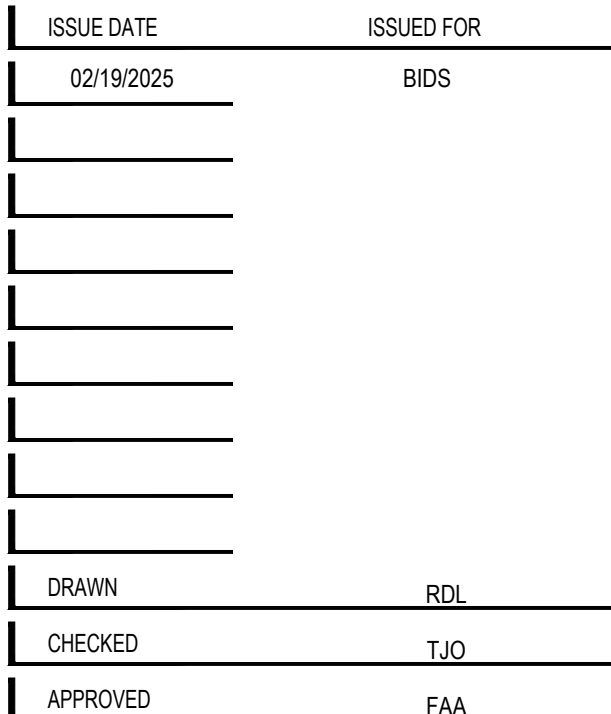

PROJECT

Livonia Public Schools
Stevenson High School
Pool Filtration Project

LIVONIA,
MICHIGAN

1 SHEET



ELECTRICAL POWER
LOWER LEVEL NEW
WORK PLAN - UNIT K

PROJECT NUMBER

2024-081

SHEET NUMBER

EP2.10K

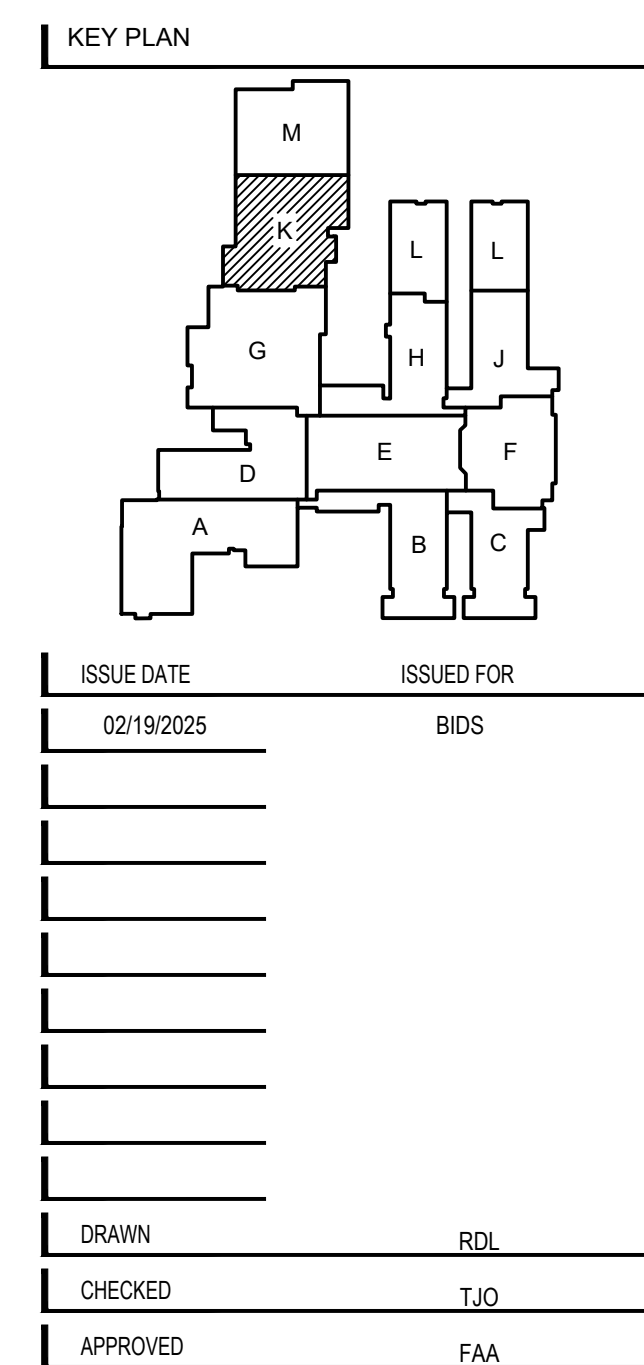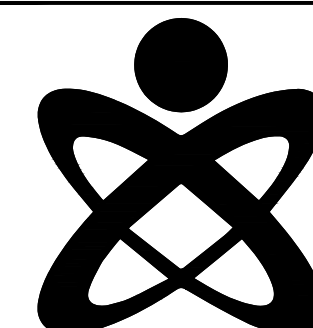

UNIFIED BUILDING
SYSTEMS ENGINEERING
69 S. GRATIOT AVE.
MT. CLEMENS, MI 48043
UBS PROJECT 029.24.17



FRENCH

2851 High Meadow Circle | Suite 100
Auburn Hills | MI 48326
248.656.1377

PROJECT

Livonia Public Schools
Stevenson High School
Pool Filtration Project

LIVONIA,
MICHIGAN

1 SHEET

ELECTRICAL POWER
FIRST FLOOR NEW
WORK PLAN - UNIT K

PROJECT NUMBER

2024-081

SHEET NUMBER

EP2.11K

—



ELECTRICAL POWER FIRST FLOOR NEW WORK PLAN - UNIT K


SCALE: 1/8" = 1'-0"

PARTS SPECIFIED IN 680(B)(1) - (B)(7)
TO BE BONDED TOGETHER USING:
SOLID COPPER CONDUCTORS, INSULATED COVERED, OR BARE, NOT SMALLER THAN 8 AWG
RIGID METAL CONDUIT OF BRASS OR OTHER IDENTIFIED CORROSION-RESISTANT METAL.



Panel Designation: (E)RP-P		Main: 100 Bussing: 100		P-P Voltage: 208 P-N Voltage: 120													
Panel Location: POOL TUNNEL		Ground Bus: STANDARD		Phase: 3													
Fed From: EXISTING		Mounting: S SURFACE		Wire: 4													
Feeder Size: EXISTING		Neutral: 100%		Min SC Interrupting Rating: EXISTING													
Remarks	Light Load	Recept Load	Cont Load	nonC Load	OC Prof	CKT	Ø A	Ø B	Ø C	CKT	OC Prof	nonC Load	Cont Load	Recept Load	Light Load	Remarks	
(U) EH-1 & UH-Z T03			1920		20	1	X			2	20		1000			CO2 PUMP	
(E) EF-I2_T01			1000		20	3	X	A		4	20					EISPACE	
(R) BRACS T03			1920		20	5	X	B		6	20					EISPACE	
(R) RECEPT_001_101_EXTERIOR			1000		20	7	X	C		8	20					EISPACE	
(R) RECEPT T03 ROOF			1000		20	9	X			10	20					EISPACE	
(R) RECEPT T03 ROOF			1000		20	11	X			12	20					EISPACE	
(E) CHEMICAL CONTROLLER, ACID			1000		20	13	X			14	20					EISPACE	
(L) LIGHTING 001, 002, 101, 102, 103			1000		20	15	X	B		16	20					EISPACE	
(E) SUMP PUMP				1000	20	17	X	C		18	20					EISPACE	
(R) RECPIT FILTER PUMP ROOM			1000		20	19	X			20						EISPACE	
(E) SPACE						21	X			22						EISPACE	
(E) SPACE						23	X			24						EISPACE	
(E) SPACE						25	X			26						EISPACE	
(E) SPACE						27	X			28						EISPACE	
(E) SPACE						29	X			30						EISPACE	
(E) SPACE						31	X			32						EISPACE	
(E) SPACE						33	X			34						EISPACE	
(E) SPACE						35	X			36						EISPACE	
(E) SPACE						37	X			38						EISPACE	
(E) SP-2			1000		20	39	X			40						EISPACE	
			1000			41	X			42						EISPACE	
Connected Load				Demand Factor				Demand Load									
Load Description	ØA	ØB	ØC	Total					ØA	ØB	ØC	Total					
Lighting or Continuous Load (Volt-Amps)	0	1000	0	1000	1.00				0	1000	0	1000					
180VA Receptacle Load (Volt-Amps)	2000	1000	1000	4000	1.00 [First 10kVA]				2000	0	1000	1000	4000				
	Amount over 10kVA				0.50 (> 10kVA)				0	0	0	0					
Continuous Load (Volt-Amps)	39.20	2000	29.20	8840	1.00				39.20	2000	29.20	8840					
Non-Continuous Load (Volt-Amps)	0	0	1000	1000	1.00				0	0	1000	1000					
Total Load (kVA)	5.92	4.00	4.92	14.84	125% of Light/Cont and Recept (<10kVA) load plus other load				5.92	4.00	4.92	14.84					
Total Ampacity (Amps)	49.3	33.3	41.0	41.2	<--- per NEC Article 215.2 ---->				49.3	33.3	41.0	41.2					
Minimum Feeder Sizing (Amps)	53.5	37.5	43.1	44.7					53.5	37.5	43.1	44.7					

ISSUE DATE	ISSUED FOR
02/19/2025	BIDS
DRAWN	RDL
CHECKED	TJO
APPROVED	FAA

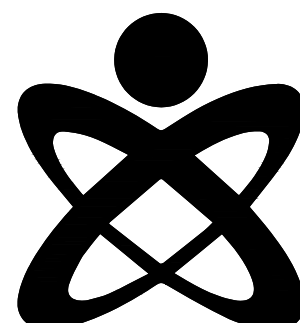

UNIFIED BUILDING
SYSTEMS ENGINEERING
69 S. GRATIOT AVE.
MT. CLEMENS, MI 48043
UBS PROJECT 029.24.17



FRENCH

**2851 High Meadow Circle | Suite 100
Auburn Hills | MI 48326
248.656.1377**

PROJECT

Livonia Public Schools
Stevenson High School
Pool Filtration Project

LIVONIA,
MICHIGAN

SHEET

ELECTRICAL DETAILS AND PANEL SCHEDULES

PROJECT NUMBER

2024-081

SHEET NUMBER

E5.00

