




- GENERAL NOTES:
- CONTRACTOR SHALL TOUCH UP PAINT TO MATCH EXISTING CONDITIONS FOR ALL AREAS OF NEW INSTALL OR DEMOLITION.
  - CONTRACTOR SHALL DEMO ALL SURFACE RACEWAY OR CONDUIT ABANDONED AS A RESULT OF DEMO.
  - AFTER CUTOVER TO NEW SYSTEMS, ALL ANALOG INTERCOM AND CLOCK CABLING SHALL BE DEMOED FROM ENDPOINT TO ENDPOINT, INCLUDING WITHIN CONDUITS AND PULL BOXES.

- SHEET NOTES:
- DEMO (E) CLOCK. DEMO CABLE TO SOURCE. PROVIDE CUSTOM BLANKING PLATE OVER CLOCK BACKBOX PER DETAIL 2/T800.
  - DEMO (E) SPEAKER AND BACKBOX. DEMO CABLE TO SOURCE AND ANY ABANDONED CONDUIT OR SURFACE RACEWAY. WATERPROOF ANY PENETRATIONS.
  - DEMO ANALOG TELEPHONE WALL PLATE. CABLING TO SOURCE, AND ABANDONED SURFACE RACEWAY.
  - DEMO ABANDONED DATA DROP. CABLING TO SOURCE, AND ABANDONED SURFACE RACEWAY.
  - DEMO ABANDONED IDF CABINET. DEMO ELECTRICAL TO CLOSEST J-BOX. DEMO BACKBOARD AS OCCURS. DEMO ALL CABLING TERMINATING AT IDF.
  - DEMO ABANDONED COAX PLATE AND CABLING TO SOURCE.
  - DEMO TELECENTER HEADEND EQUIPMENT INCLUDING RACK. DELIVER HEADEND UNIT TO DISTRICT ELECTRONICS SHOP. SEE PICTURE DETAIL.
  - DEMO CLOCK POWER SUPPLY AND SAFE OFF POWER.
  - DEMO ABANDONED AP MOUNT ON WALL, AND ABANDONED CABLING AS OCCURS.
  - DEMO INTERCOM, CLOCK, AND COAX CABLING AT STC, AS OCCURS. SEE PICTURE DETAIL.

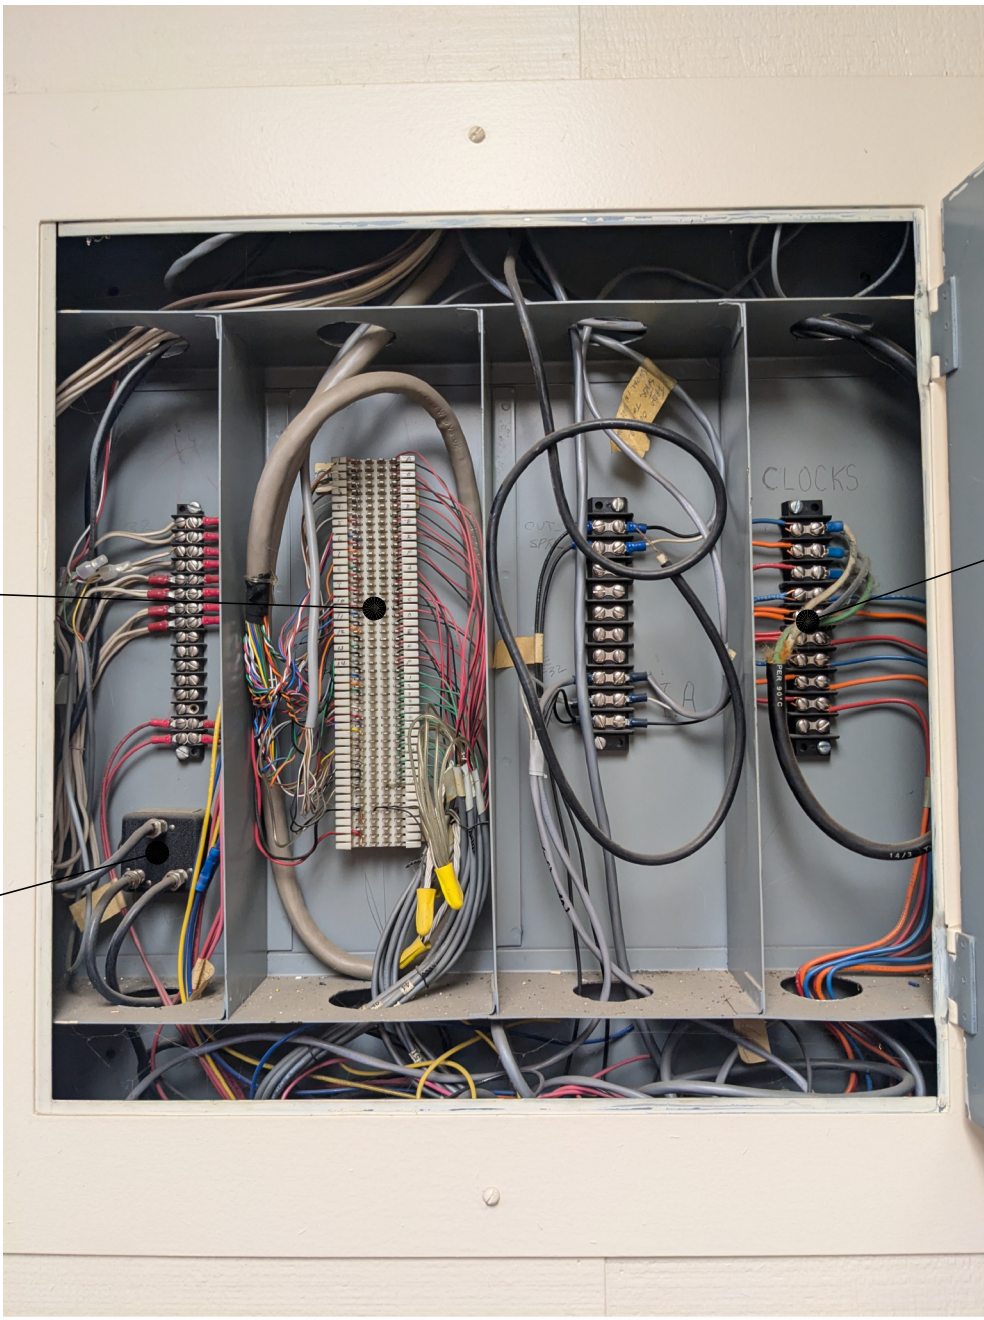

DEMO SPEAKER/PHONE  
CABLING AND 66 BLOCK

DEMO CLOCK  
CABLING AND  
TERMINAL BLOCK

DEMO COAX  
CABLING AND  
DISTRIBUTION  
BLOCK

PICTURE DETAIL - STC DEMO SCOPE (TYP.)

**SITE PLAN - DEMO**

SCALE: 1"=20'-0"

0 20 40



**KMM SERVICES, INC**  
TECHNOLOGY & FIRE LIFE SAFETY

5433 El Camino Ave., Suite 5  
Carmichael, CA 95608  
Office: (916) 359-4000 www.kmm-services.com

LICENSE STAMPS

REGISTERED COMMUNICATIONS  
DISTRIBUTION DESIGNER  
BICSI  
DONNY KASSFROM  
Signature  
EXPIRES 12/31/2027  
Reg. No. 163629

Copyright © 2025  
These drawings and specifications and the ideas, designs and arrangements represented thereby are and shall remain the property of KMM Services, Inc. and no part thereof shall be copied, disclosed to others, or used in connection with any other work or project other than the specific project for which they have been prepared and developed without the written consent of KMM Services, Inc. Visual contact with these drawings or specifications shall constitute conclusive evidence of these restrictions.

IF DRAWING IS NOT 30"x42" IT IS A REDUCED PRINT

| SHEET REVISIONS |             |            |
|-----------------|-------------|------------|
| DELTA           | DESCRIPTION | DATE       |
| ADDENDUM 001    |             | 2025-08-29 |
|                 |             |            |
|                 |             |            |
|                 |             |            |
|                 |             |            |
|                 |             |            |

SITE KEY PLAN

PROJECT  
**SACRAMENTO  
CITY USD**  
DAVID LUBIN ES  
TELECENTER UPGRADE  
3535 M STREET  
SACRAMENTO, CA, 95816

SHEET TITLE  
**SITE PLAN - DEMO**

DRAWING STATUS  
**CONSTRUCTION DRAWINGS**


|               |            |
|---------------|------------|
| PROJECT NO:   |            |
| BID PACKAGE:  | 0059-411   |
| DESIGNED BY:  | CS         |
| CHECKED BY:   | SD         |
| ISSUE DATE:   | 2025-07-21 |
| WORKING DATE: | 2025-08-29 |

REVISION

SHEET **T010**



TECHNOLOGY SITE PLAN - EXTERIOR SPEAKER COVERAGE

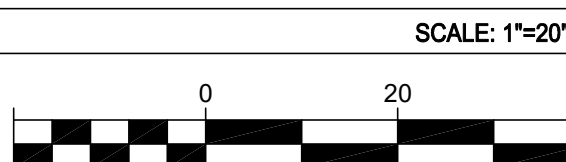

KMM SERVICES, INC  
TECHNOLOGY & FIRE LIFE SAFETY

5433 El Camino Ave. Suite 5  
Carmichael, CA 95608  
Office: (916) 359-4000 www.kmm-services.com

LICENSE STAMPS



Copyright © 2025  
These drawings and specifications and the ideas, designs and arrangements represented thereby are and shall remain the property of KMM Services, Inc. and no part thereof shall be copied, disclosed to others, or used in connection with any other work or project other than the specific project for which they have been prepared and developed without the written consent of KMM Services, Inc. Visual contact with these drawings or specifications shall constitute conclusive evidence of these restrictions.

IF DRAWING IS NOT 30"X42" IT IS A REDUCED PRINT

SHEET REVISIONS

| DELTA        | DESCRIPTION | DATE       |
|--------------|-------------|------------|
| ADDENDUM 001 |             | 2025-08-29 |

SITE KEY PLAN

PROJECT  
SACRAMENTO  
CITY USD  
DAVID LUBIN ES  
TELECENTER UPGRADE  
3535 M STREET  
SACRAMENTO, CA, 95816


SHEET TITLE  
SITE PLAN -  
EXTERIOR SPEAKER  
COVERAGE

DRAWING STATUS  
CONSTRUCTION DRAWINGS

|               |            |
|---------------|------------|
| PROJECT NO:   |            |
| BID PACKAGE:  | 0059-411   |
| DESIGNED BY:  | CS         |
| CHECKED BY:   | SD         |
| ISSUE DATE:   | 2025-07-21 |
| WORKING DATE: | 2025-08-29 |

REVISION

SHEET  
T101

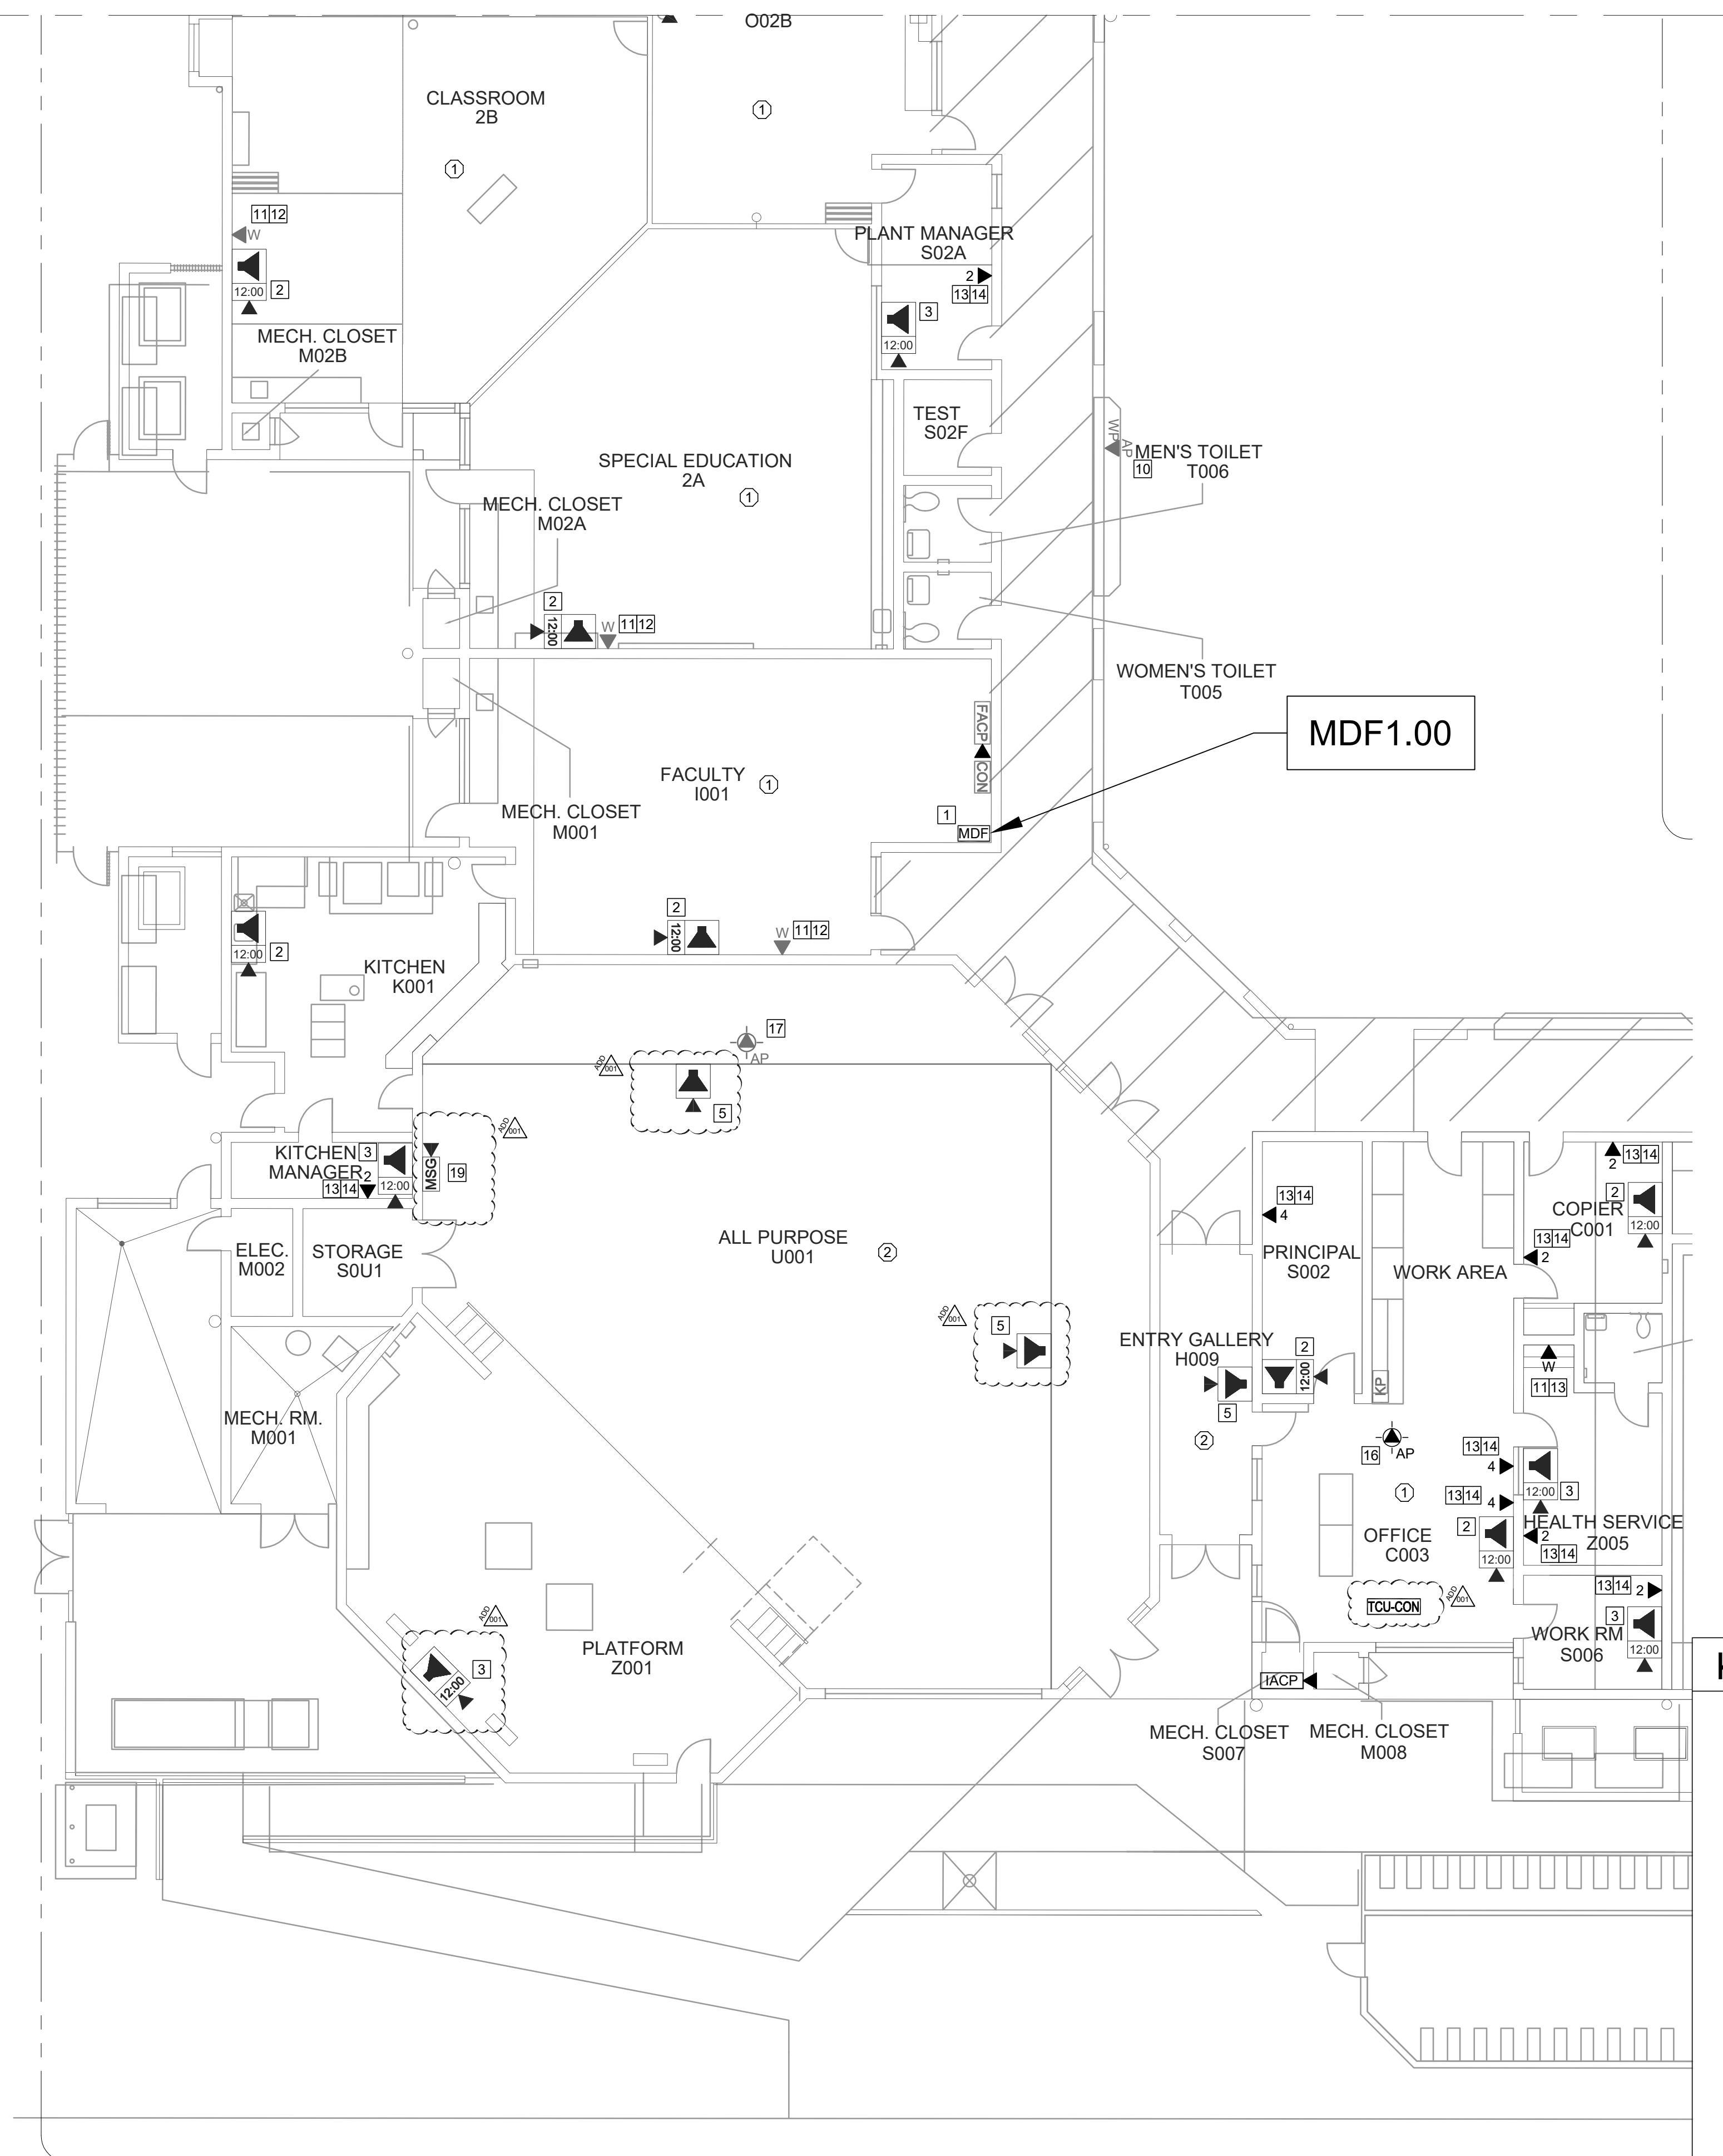


SCALE: 1/8"=1'

A horizontal graphic scale bar with a black and white checkerboard pattern. It is marked with the numbers 0, 4, 8, and 12, representing feet. The bar is divided into four equal segments of 4 feet each.

## SHEET NOTES:

- 1 REWORK MDMFID PER RACK ELEVATION. SEE T400T0401.
- 2 REMOVE (E) SPEAKER. PROVIDE (N) COMBO BOX WITH (N) SPEAKER, (N) CLASSROOM IP MODULE, AND (N) IP CLOCK. PROVIDE (N) 1 EA. CAT6A DATA DROP. INTERCEPT CONDUIT ABOVE T-BAR AND FEED THROUGH (E) CLOCK BACKBOX.
- 3 PROVIDE (N) COMBO BOX WITH (N) SPEAKER, (N) CLASSROOM IP MODULE, AND (N) IP CLOCK. PROVIDE (N) 1 EA. CAT6A DATA DROP. FISH THROUGH WALL TO (N) CUT-IN BOX BEHIND COMBO BACKBOX.
- 4 PROVIDE (N) EXTERIOR SPEAKER WITH (N) EXTERIOR BACKBOX. PROVIDE (N) INTERIOR ENCLOSURE WITH (N) CLASSROOM IP MODULE. PROVIDE (N) 1 EA. CAT6A DATA DROP AT INTERIOR ENCLOSURE. REMOVE (E) SPEAKER, AS OCCURS.
- 5 PROVIDE (N) BACKBOX WITH (N) SPEAKER AND (N) CLASSROOM IP MODULE. PROVIDE (N) 1 EA. CAT6A DATA DROP.
- 6 REMOVE (E) SPEAKER AND (E) CLOCK FROM (E) EXECUTION. BAFFLE PROVIDE (N) SPEAKER WITH (N) CLASSROOM IP MODULE AND MOUNT TO (E) BAFFLE. PROVIDE (N) CLOCK AND MOUNT ON (N) PLASTIC PLATE. PROVIDE (N) 1 EA. CAT6A DATA DROP. INTERCEPT CONDUIT ABOVE T-BAR AND FEED INTO (E) CLOCK BACKBOX. SEE DETAIL 1/7801.
- 7 PROVIDE (N) LAY-IN SPEAKER AND (N) CLASSROOM IP MODULE. PROVIDE 1 EA. (N) CAT6A DATA DROP.
- 8 REMOVE (E) CLOCK/SPEAKER COMBO. PROVIDE (N) COMBO BOX WITH (N) SPEAKER, (N) CLASSROOM IP MODULE, AND (N) IP CLOCK. PROVIDE (N) 1 EA. CAT6A DATA DROP. FISH THROUGH WALL TO (N) CUT-IN BOX BEHIND COMBO BACKBOX.
- 9 REMOVE (E) CLOCK/SPEAKER COMBO. PROVIDE (N) COMBO BOX WITH (N) SPEAKER, (N) CLASSROOM IP MODULE, AND (N) IP CLOCK. PROVIDE (N) 1 EA. CAT6A DATA DROP. PROVIDE WM2300 TO NEAREST DATA RACEWAY OR J-BOX.
- 10 PROVIDE (N) 1 EA. CAT6A DATA DROP AT (E) EXTERIOR AP. REWORK AND PROVIDE REQUIRED COMPONENTS PER DETAIL 1271801, 137801.
- 11 PROVIDE (N) PHONE HANGER WALL PLATE. OPTRONICS PIN MOUNTED AT (E) OR (N) OF RACK. PROVIDE (N) DATA LOCATION.
- 12 REPLACE (E) SURFACE RACEWAY AND BOXES WITH (N) WM2300 AND BOXES. REWORK (E) DATA DROPS INTO (N) RACEWAY. SEE PICTURE DETAIL SHEET 1203 FOR TYPICAL SCOPE.
- 13 PROVIDE (N) CAT6A DATA DROP. QUANTITY INDICATED.
- 14 PROVIDE CUT-IN BOX AND FISH TO ACCESSIBLE CEILING.
- 15 PROVIDE (N) WM2300 TO ACCESSIBLE CEILING.
- 16 PROVIDE (N) 1 EA. CAT6A DATA DROP FOR (E) WIRELESS AP.
- 17 PROVIDE (N) RIGHT ANGLE WALL MOUNT AT (E) AP. OBERON P/N 1006-COAP9136.
- 18 PROVIDE (N) 1 EA. DEDICATED 120V 20A CIRCUIT IN QUAD BOX ON REAR PAN OF (E) IDF RACK.
- 19 PROVIDE (N) LARGE MESSAGE BOARD WITH PROTECTIVE COVER. PROVIDE (N) 1 EA. CAT6A DATA DROP.

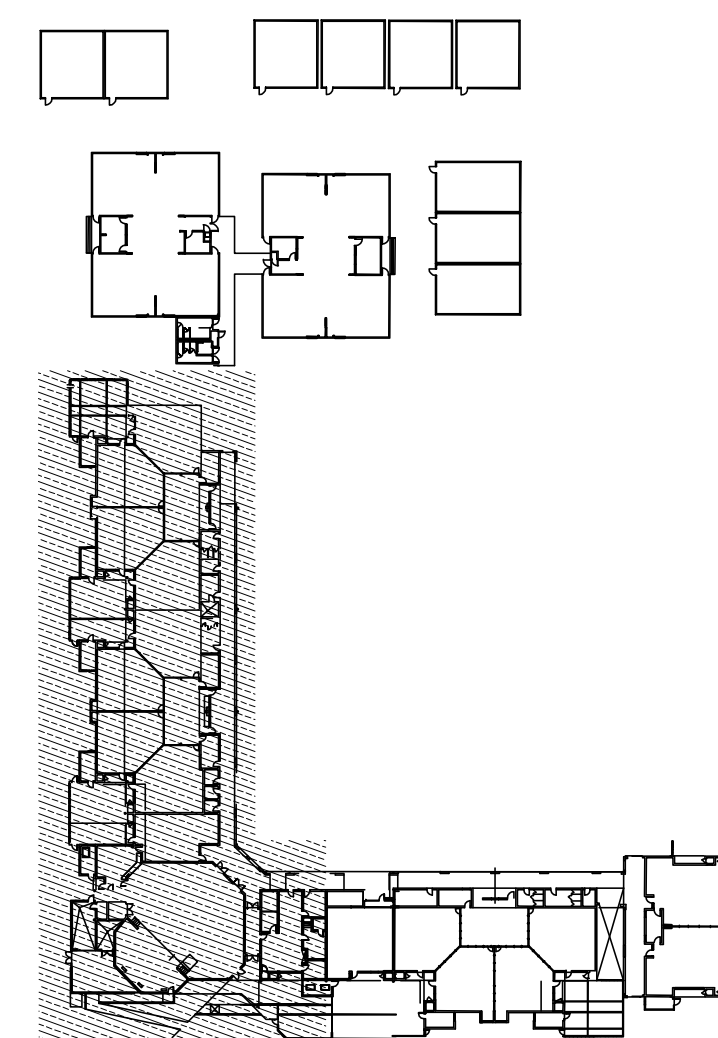

# T200

