 





1. FINAL LOCATIONS TO BE FIELD VERIFIED WITH OWNER PRIOR TO INSTALLATION
2. PROVIDE SAFETY CABLES FOR ALL SPEAKERS.

EC	EQUIPMENT CABINET
S	SPEAKER
TP	TOUCH PANEL
M	MICROPHONE
MA	MIC/AUX INPUT
V	HDMI INPUT PLATE
P	CEILING MOUNTED PROJECTOR
SCREEN	
PROJECTION SCREEN	



2 CAFETERIA AUDIO VIDEO SCHEMATIC
NTS

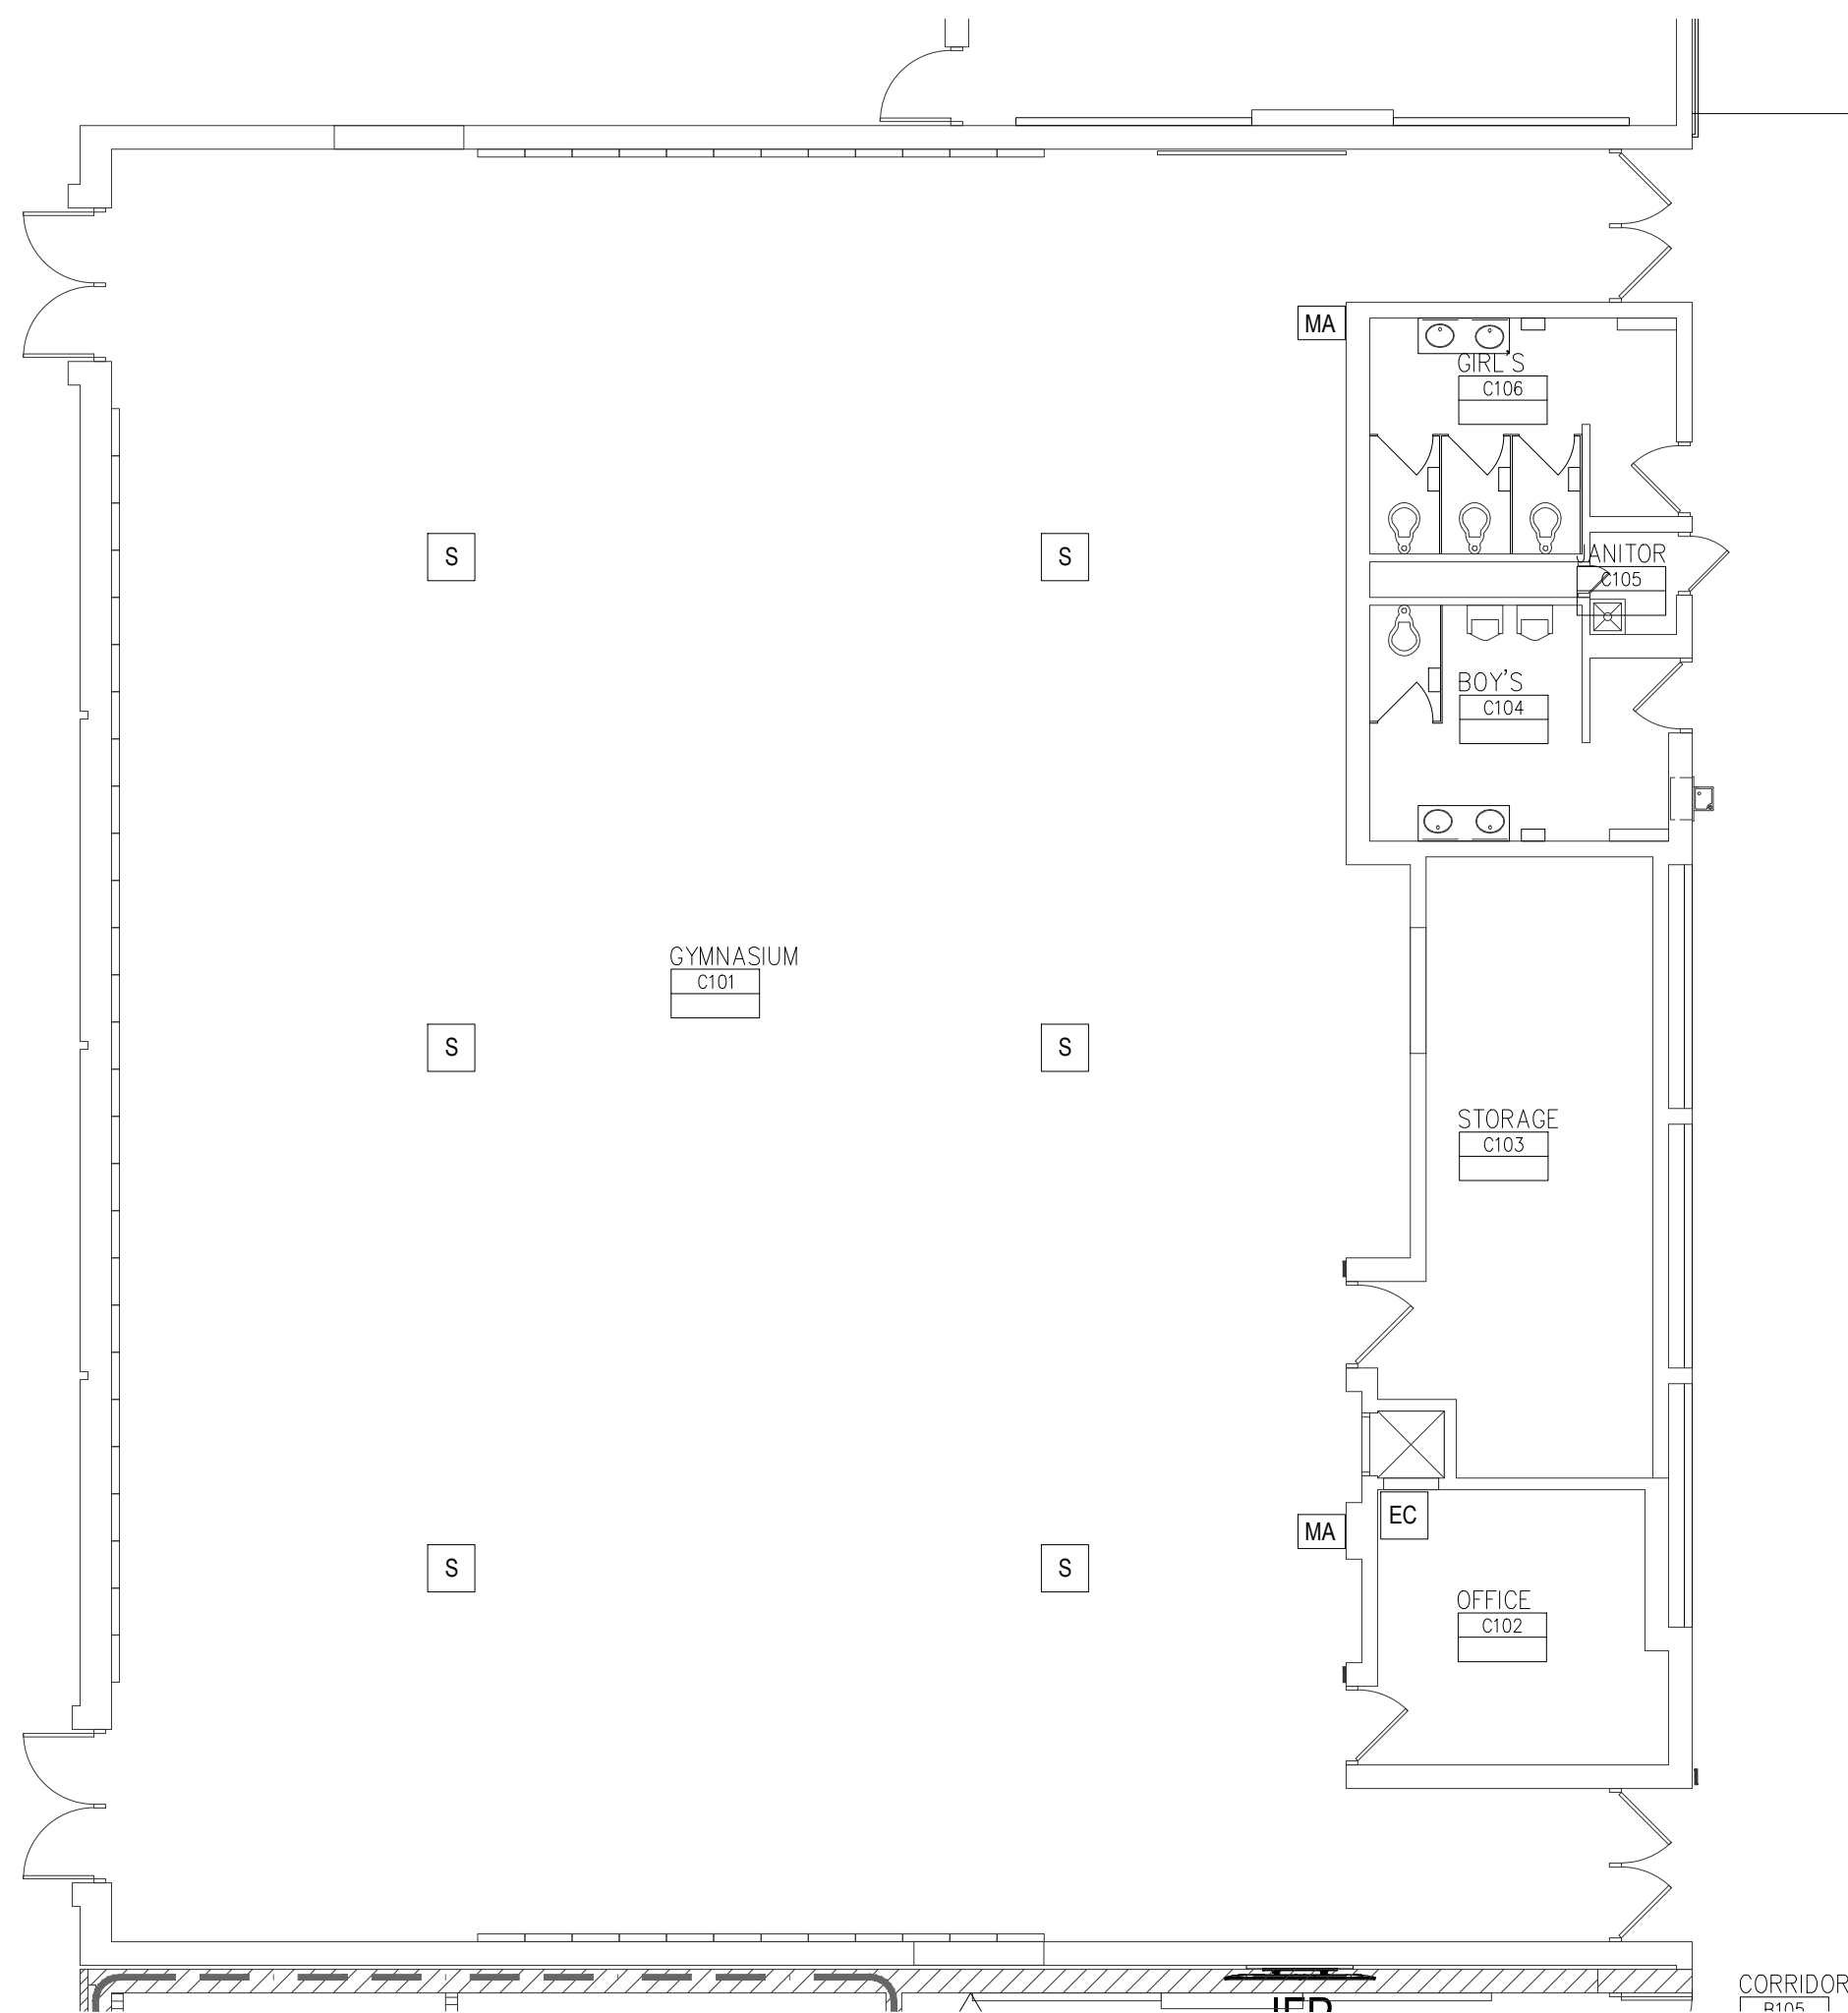


1 GYMNASIUM AUDIO VIDEO SYSTEM
1/8" = 1'-0"

GENERAL AUDIO VIDEO NOTES:

1. FINAL LOCATIONS TO BE FIELD VERIFIED WITH OWNER PRIOR TO INSTALLATION.
2. PROVIDE SAFETY CABLES FOR ALL SPEAKERS.

AUDIO VIDEO FLOOR PLAN SYMBOL LEGEND:

- EC EQUIPMENT CABINET
- S SPEAKER
- M MICROPHONE
- MA MIC/AUX INPUT

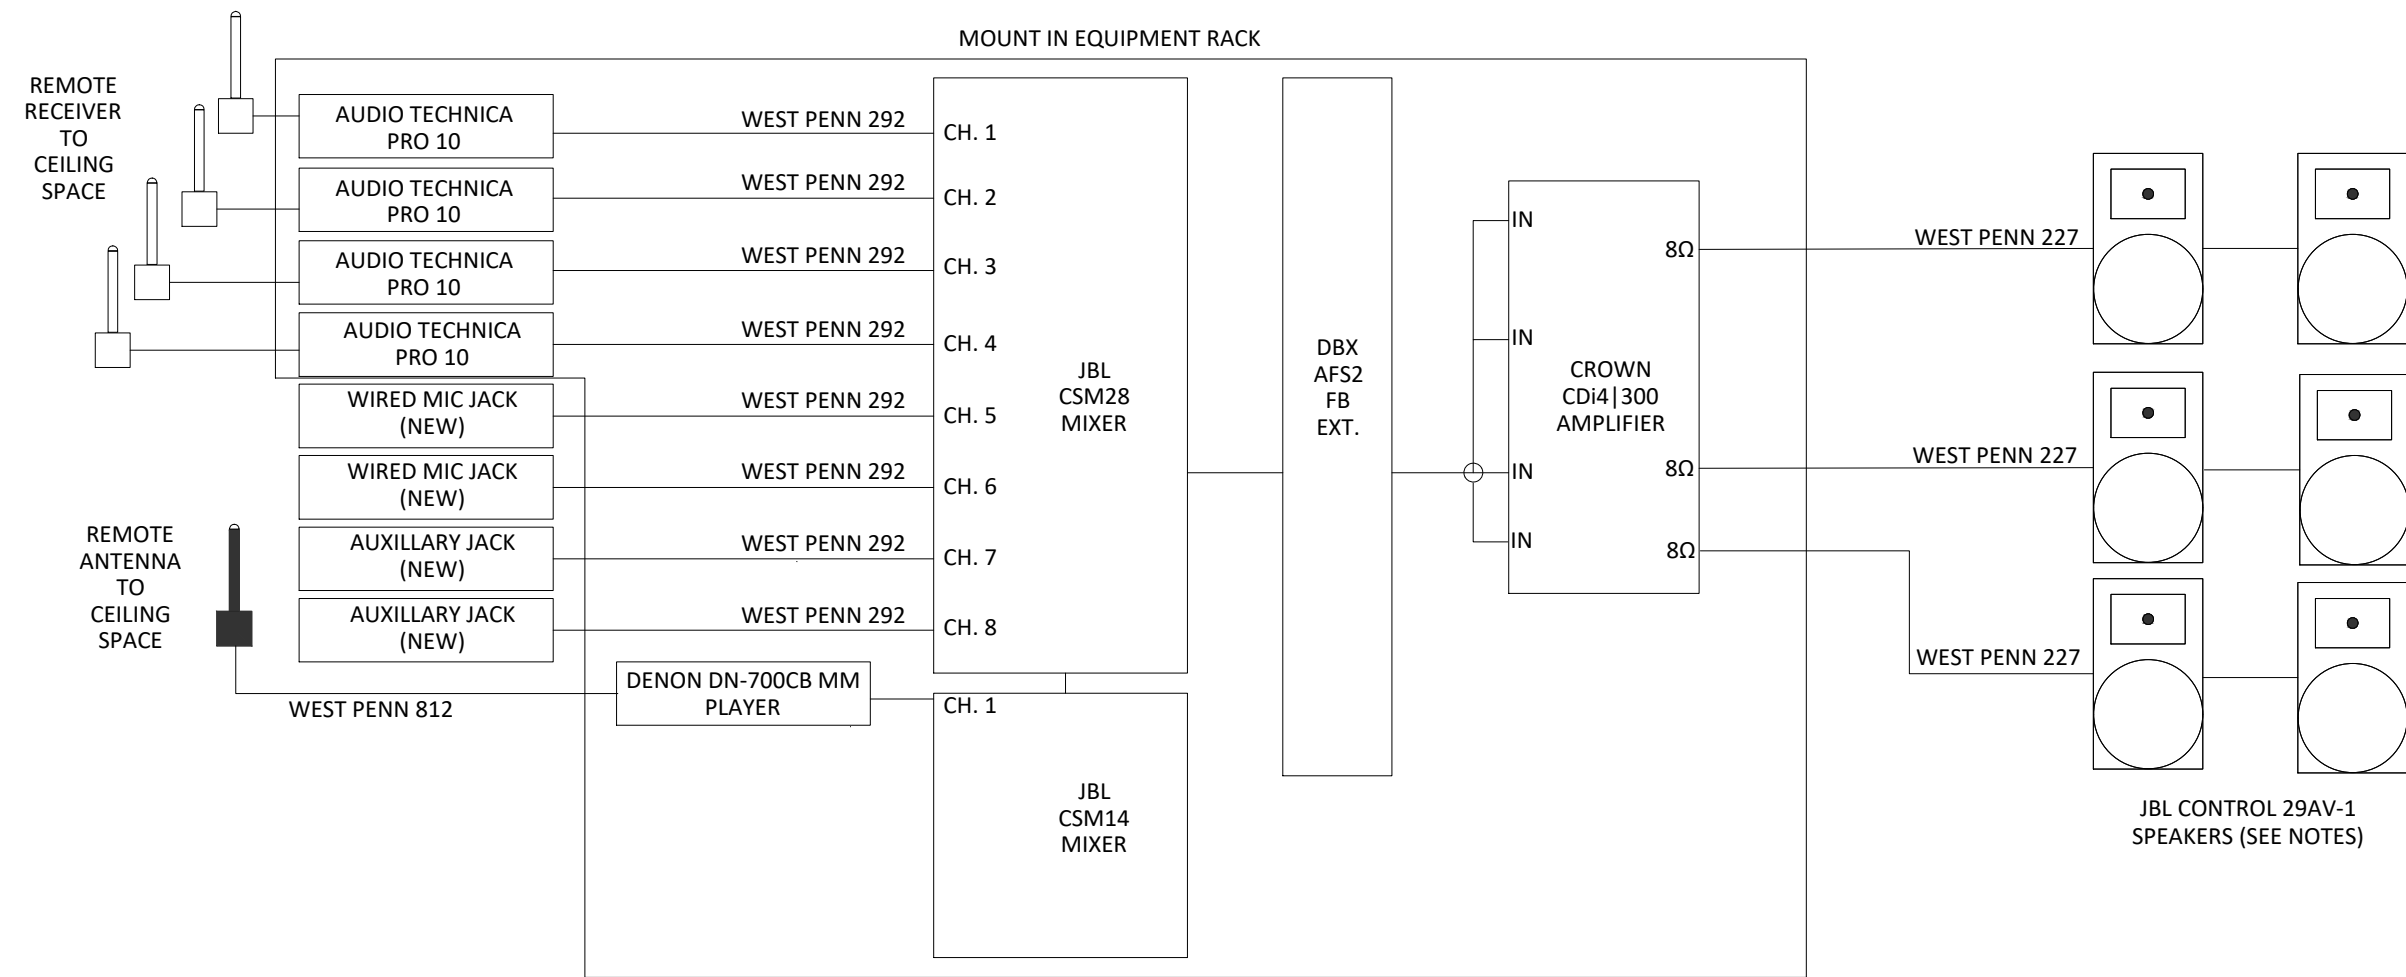

1. AT MORaine ELEMENTARY - REUSE EXISTING SIX SPEAKERS.
2. AT RIDGEWOOD, WINCHESTER AND SILVER SPRINGS ELEMENTARY - ADD TWO (2) SPEAKERS TO EXISTING. VERIFY EXISTING SPEAKER TYPE PRIOR TO ORDERING. ASSUME JBL CONTROL 29AV-1 FOR BID PURPOSES.
3. AT THORNTON CREEK - REMOVE EXISTING ANTIQUE SPEAKERS.
4. AT COOKE SCHOOL - REUSE EXISTING SIX SPEAKERS.

1 GYMNASIUM AUDIO VIDEO SCHEMATIC
NTS

KEY PLAN

OWNER

Northville Public
Schools

PROJECT NAME

Audio and Video Systems

Northville, MI 48167

PROJECT NO.

25-NPS-AVS-01

ISSUES / REVISIONS

03.12.2025 BIDS

DRAWN BY

BMJ

CHECKED BY

BG

APPROVED BY


SJB

SHEET NAME

AMERMAN
ELEMENTARY GYM
AVS

SHEET NO.

TA102

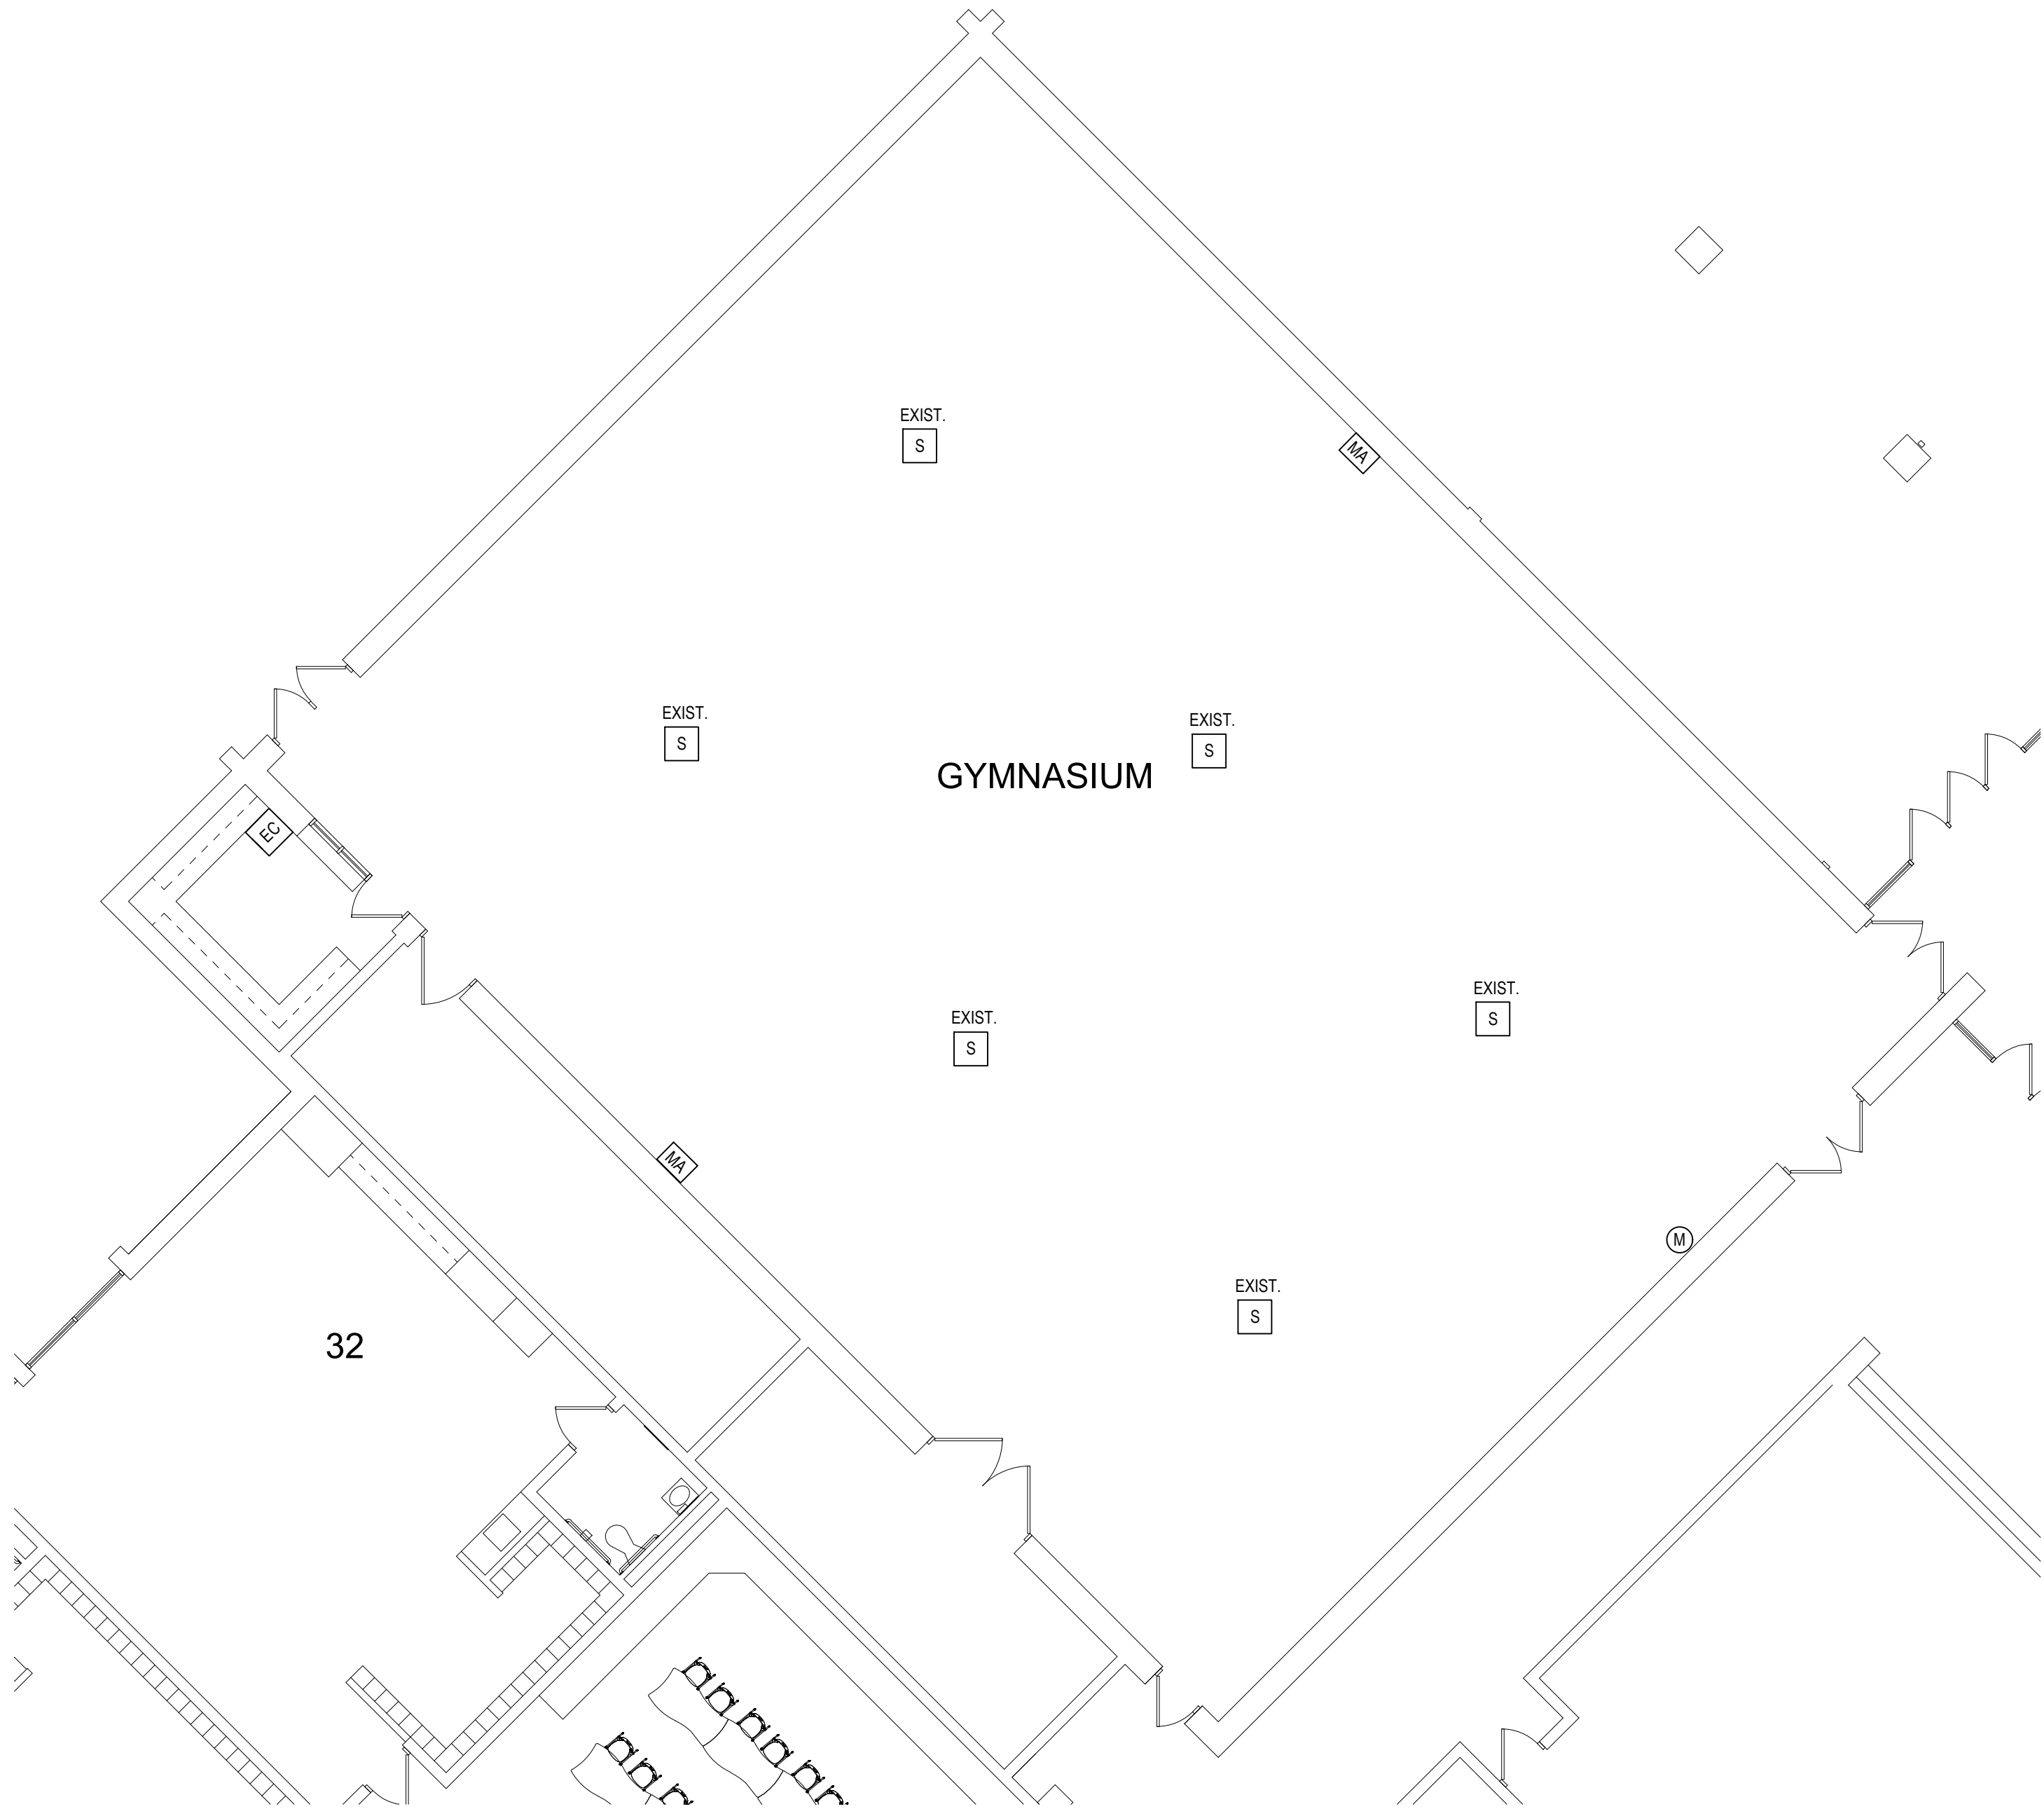


1 GYMNASIUM AUDIO VIDEO SYSTEM
1/8" = 1'-0"

- GENERAL AUDIO VIDEO NOTES:
1. FINAL LOCATIONS TO BE FIELD VERIFIED WITH OWNER PRIOR TO INSTALLATION.
 2. PROVIDE SAFETY CABLES FOR ALL SPEAKERS.

AUDIO VIDEO FLOOR PLAN SYMBOL LEGEND:

- ER EQUIPMENT CABINET
S SPEAKER
M MICROPHONE
MA MIC/AUX INPUT

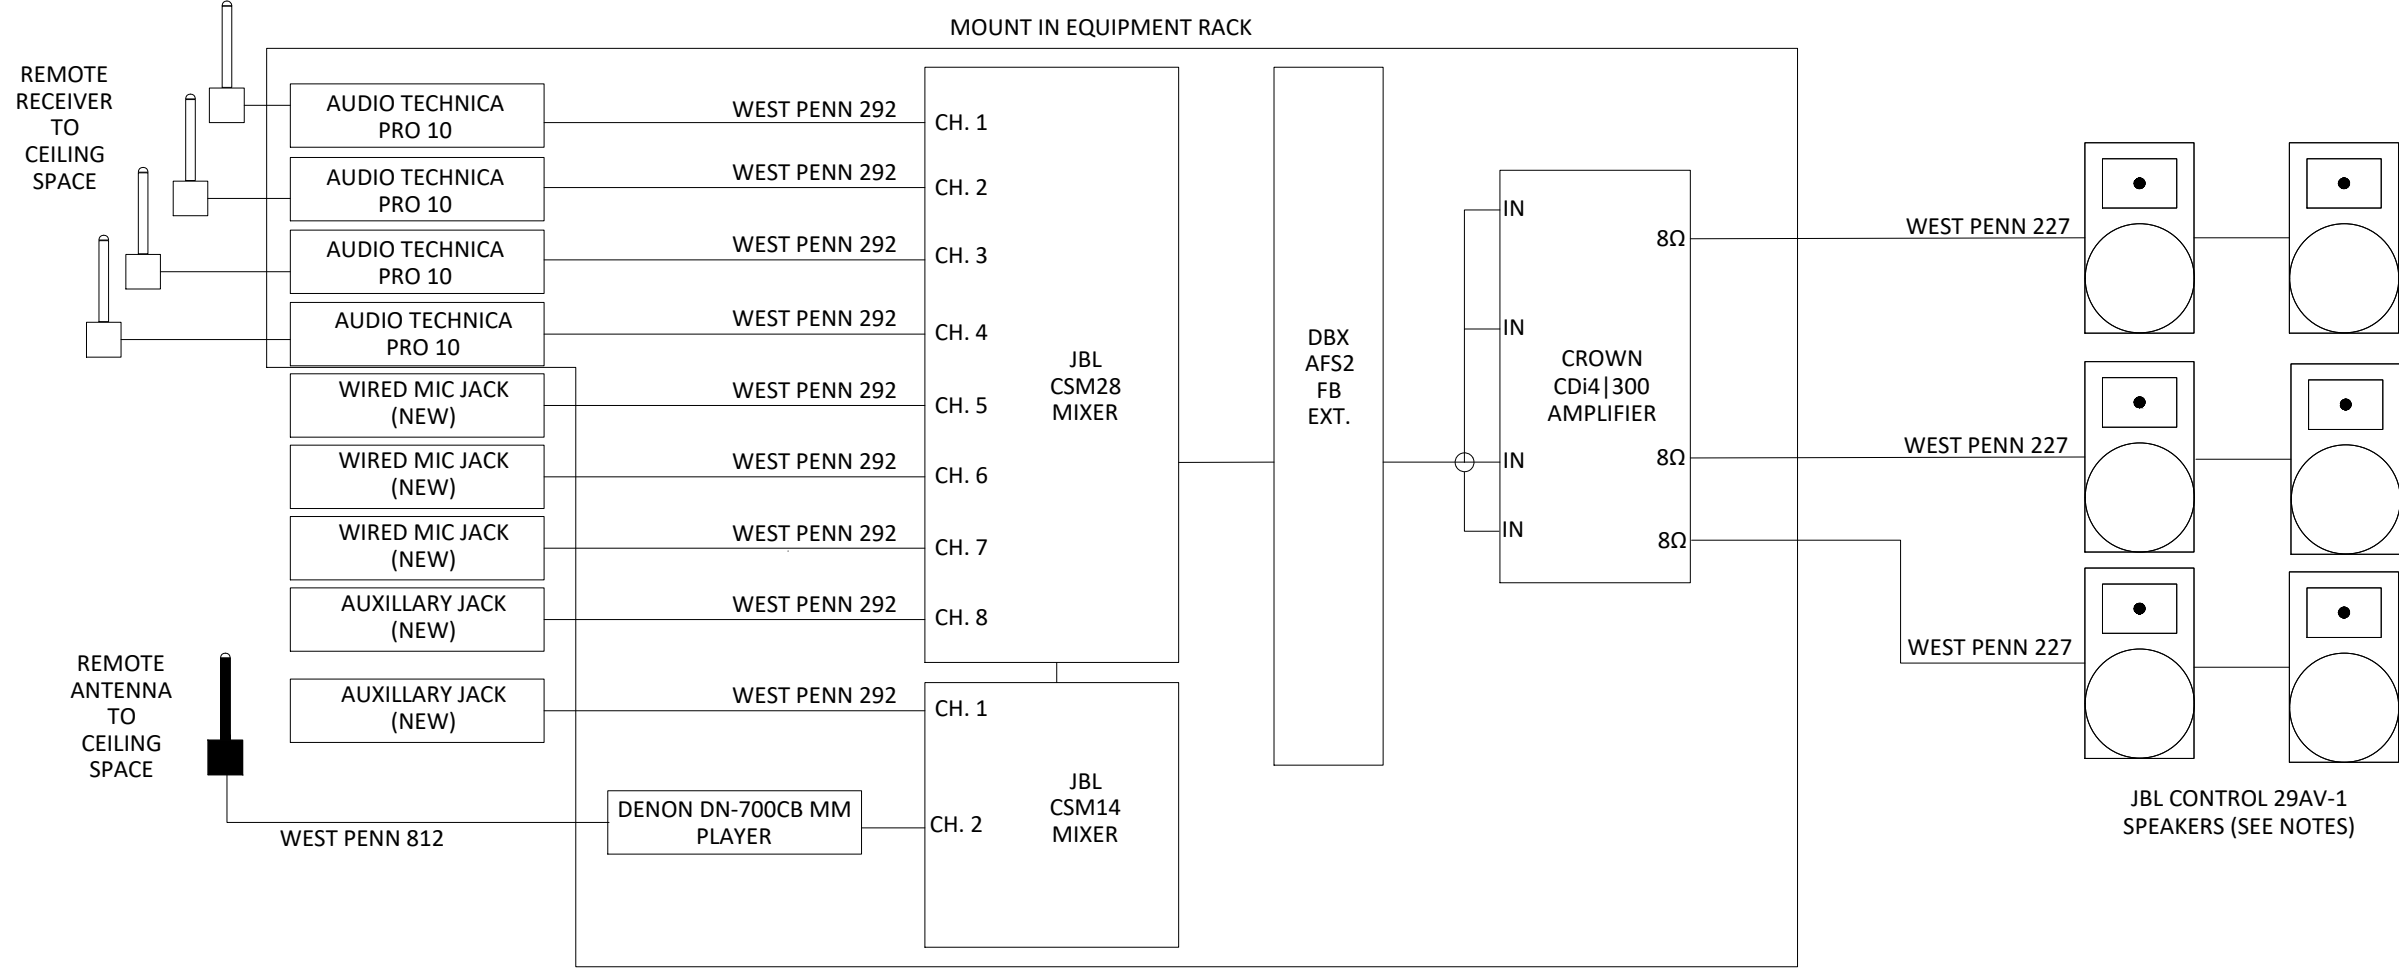

1. AT MORaine ELEMENTARY - REUSE EXISTING SIX SPEAKERS.
2. AT RIDGEWOOD, WINCHESTER AND SILVER SPRINGS ELEMENTARY - ADD TWO (2) SPEAKERS TO EXISTING. VERIFY EXISTING SPEAKER TYPE PRIOR TO ORDERING. ASSUME JBL CONTROL 29AV-1 FOR BID PURPOSES.
3. AT THORNTON CREEK - REMOVE EXISTING ANTIQUE SPEAKERS.
4. AT COOKE SCHOOL - REUSE EXISTING SIX SPEAKERS.

KEY PLAN

OWNER

Northville Public
Schools

PROJECT NAME

Audio and Video Systems

Northville, MI 48167

PROJECT NO.

25-NPS-AVS-01

ISSUES / REVISIONS

03.12.2025 BIDS

DRAWN BY

BMJ

CHECKED BY

BG

APPROVED BY


SJB

SHEET NAME

MORaine
ELEMENTARY GYM
AVS

SHEET NO.

TA103

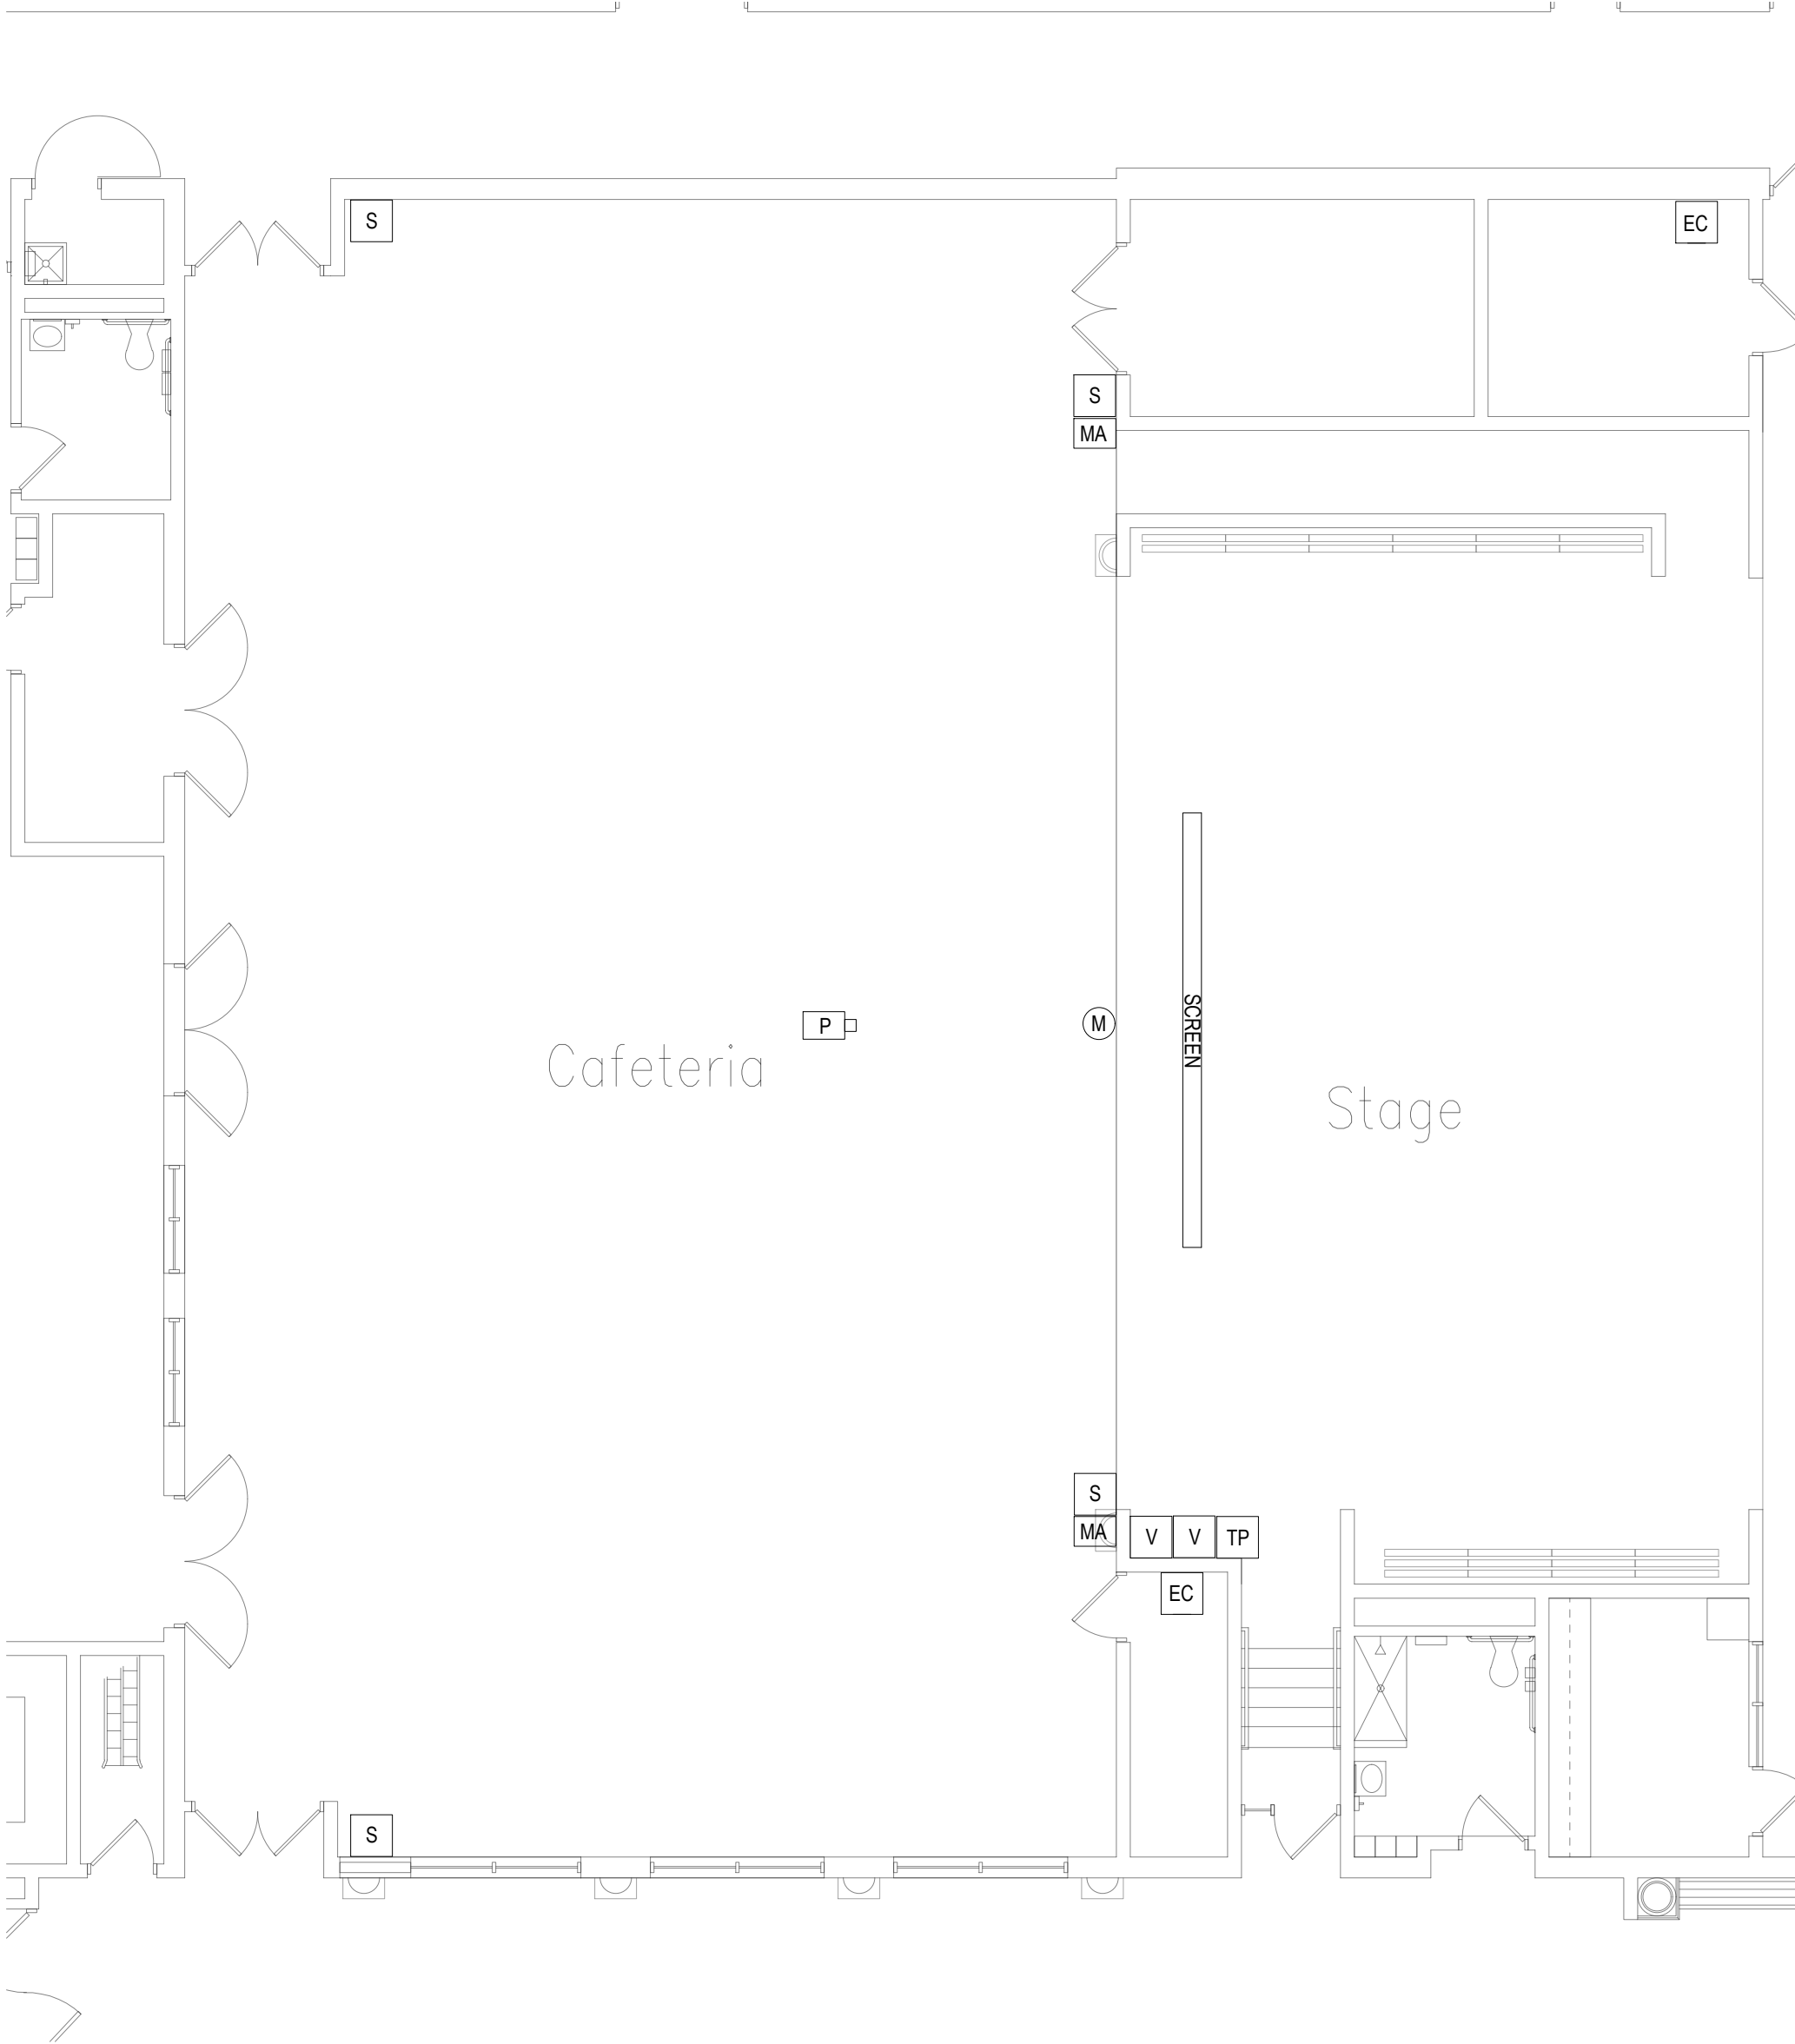

1 CAFETERIA AUDIO VIDEO SYSTEMS
1/8" = 1'-0"

GENERAL AUDIO VIDEO NOTES:

1. FINAL LOCATIONS TO BE FIELD VERIFIED WITH OWNER PRIOR TO INSTALLATION.
2. PROVIDE SAFETY CABLES FOR ALL SPEAKERS.

AUDIO VIDEO FLOOR PLAN SYMBOL LEGEND:

- EC EQUIPMENT CABINET
- S SPEAKER
- TP TOUCH PANEL
- M MICROPHONE
- MA MIC/AUX INPUT
- V HDMI VIDEO INPUT PLATE
- P CEILING MOUNTED PROJECTOR
- SCREEN
PROJECTION SCREEN

KEY PLAN

OWNER

Northville Public
Schools

PROJECT NAME

Audio and Video Systems

Northville, MI 48167

PROJECT NO.

25-NPS-AVS-01

ISSUES / REVISIONS

03.12.2025 BIDS

DRAWN BY

BMJ

CHECKED BY

BG

APPROVED BY


SJB

SHEET NAME


RIDGE WOOD
ELEMENTARY
CAFETERIA AVS

SHEET NO.

TA104

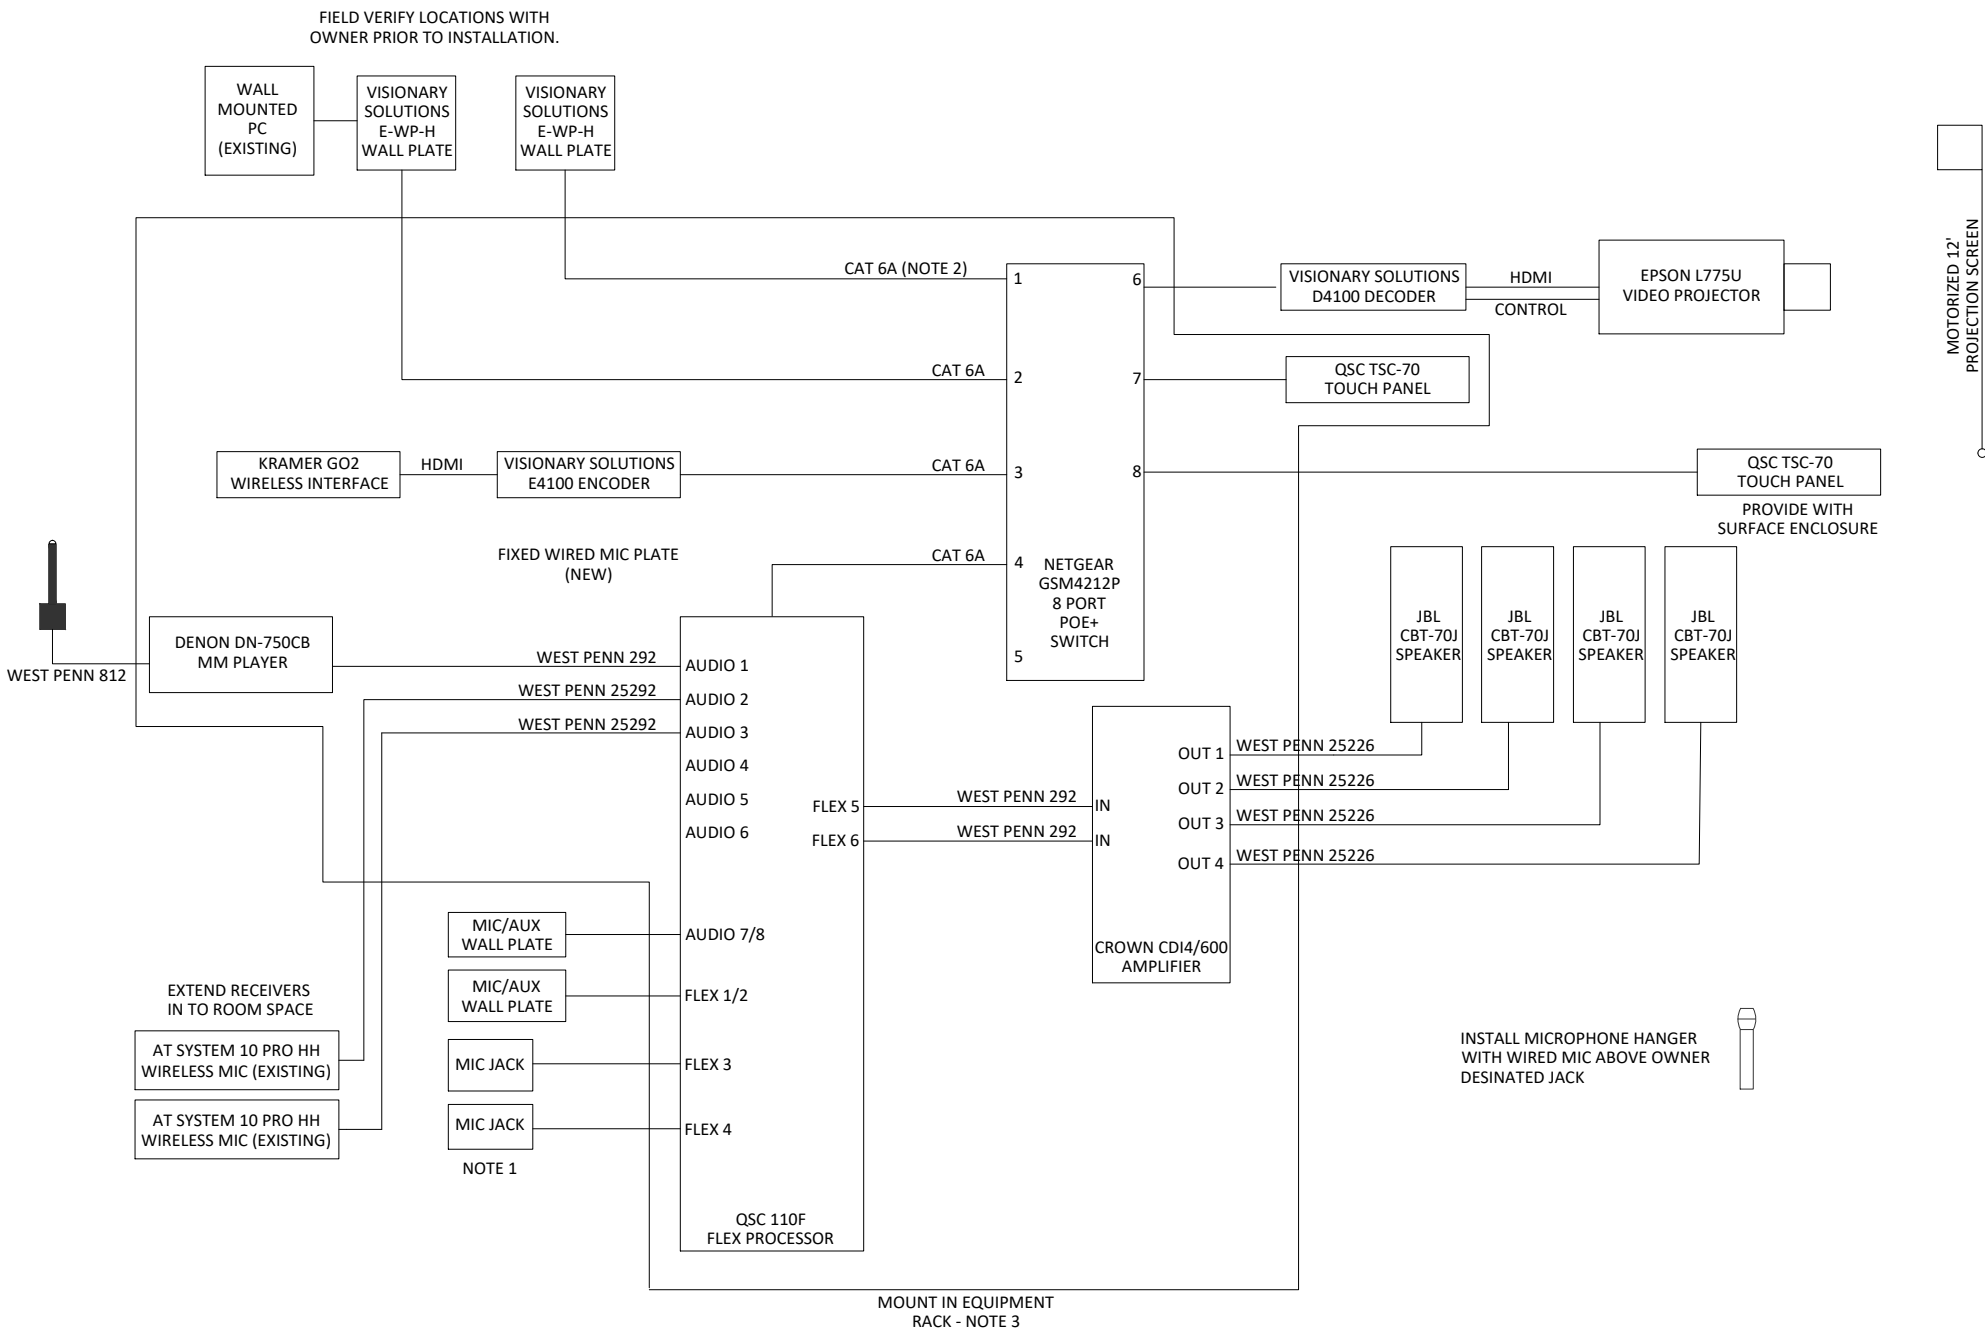

NOTE 1 - NUMBER OF MIC JACKS PER ROOM MAY DIFFER. SEE PLANS. ALL JACKS ARE TO BE REWIRED WITH WEST PENN 25292.
NOTE 2 - ALL CAT6A CABLES SHALL BE SHIELDED AND PLenum RATED. PROVIDE SHIELDED CONNECTORS FOR ALL CONNECTIONS
NOTE 3 - REMOVE EXISTING RACK. REUSE EXISTING AUDIO TECHNICA SYSTEM 10 PRO WIRELESS MICROPHONES

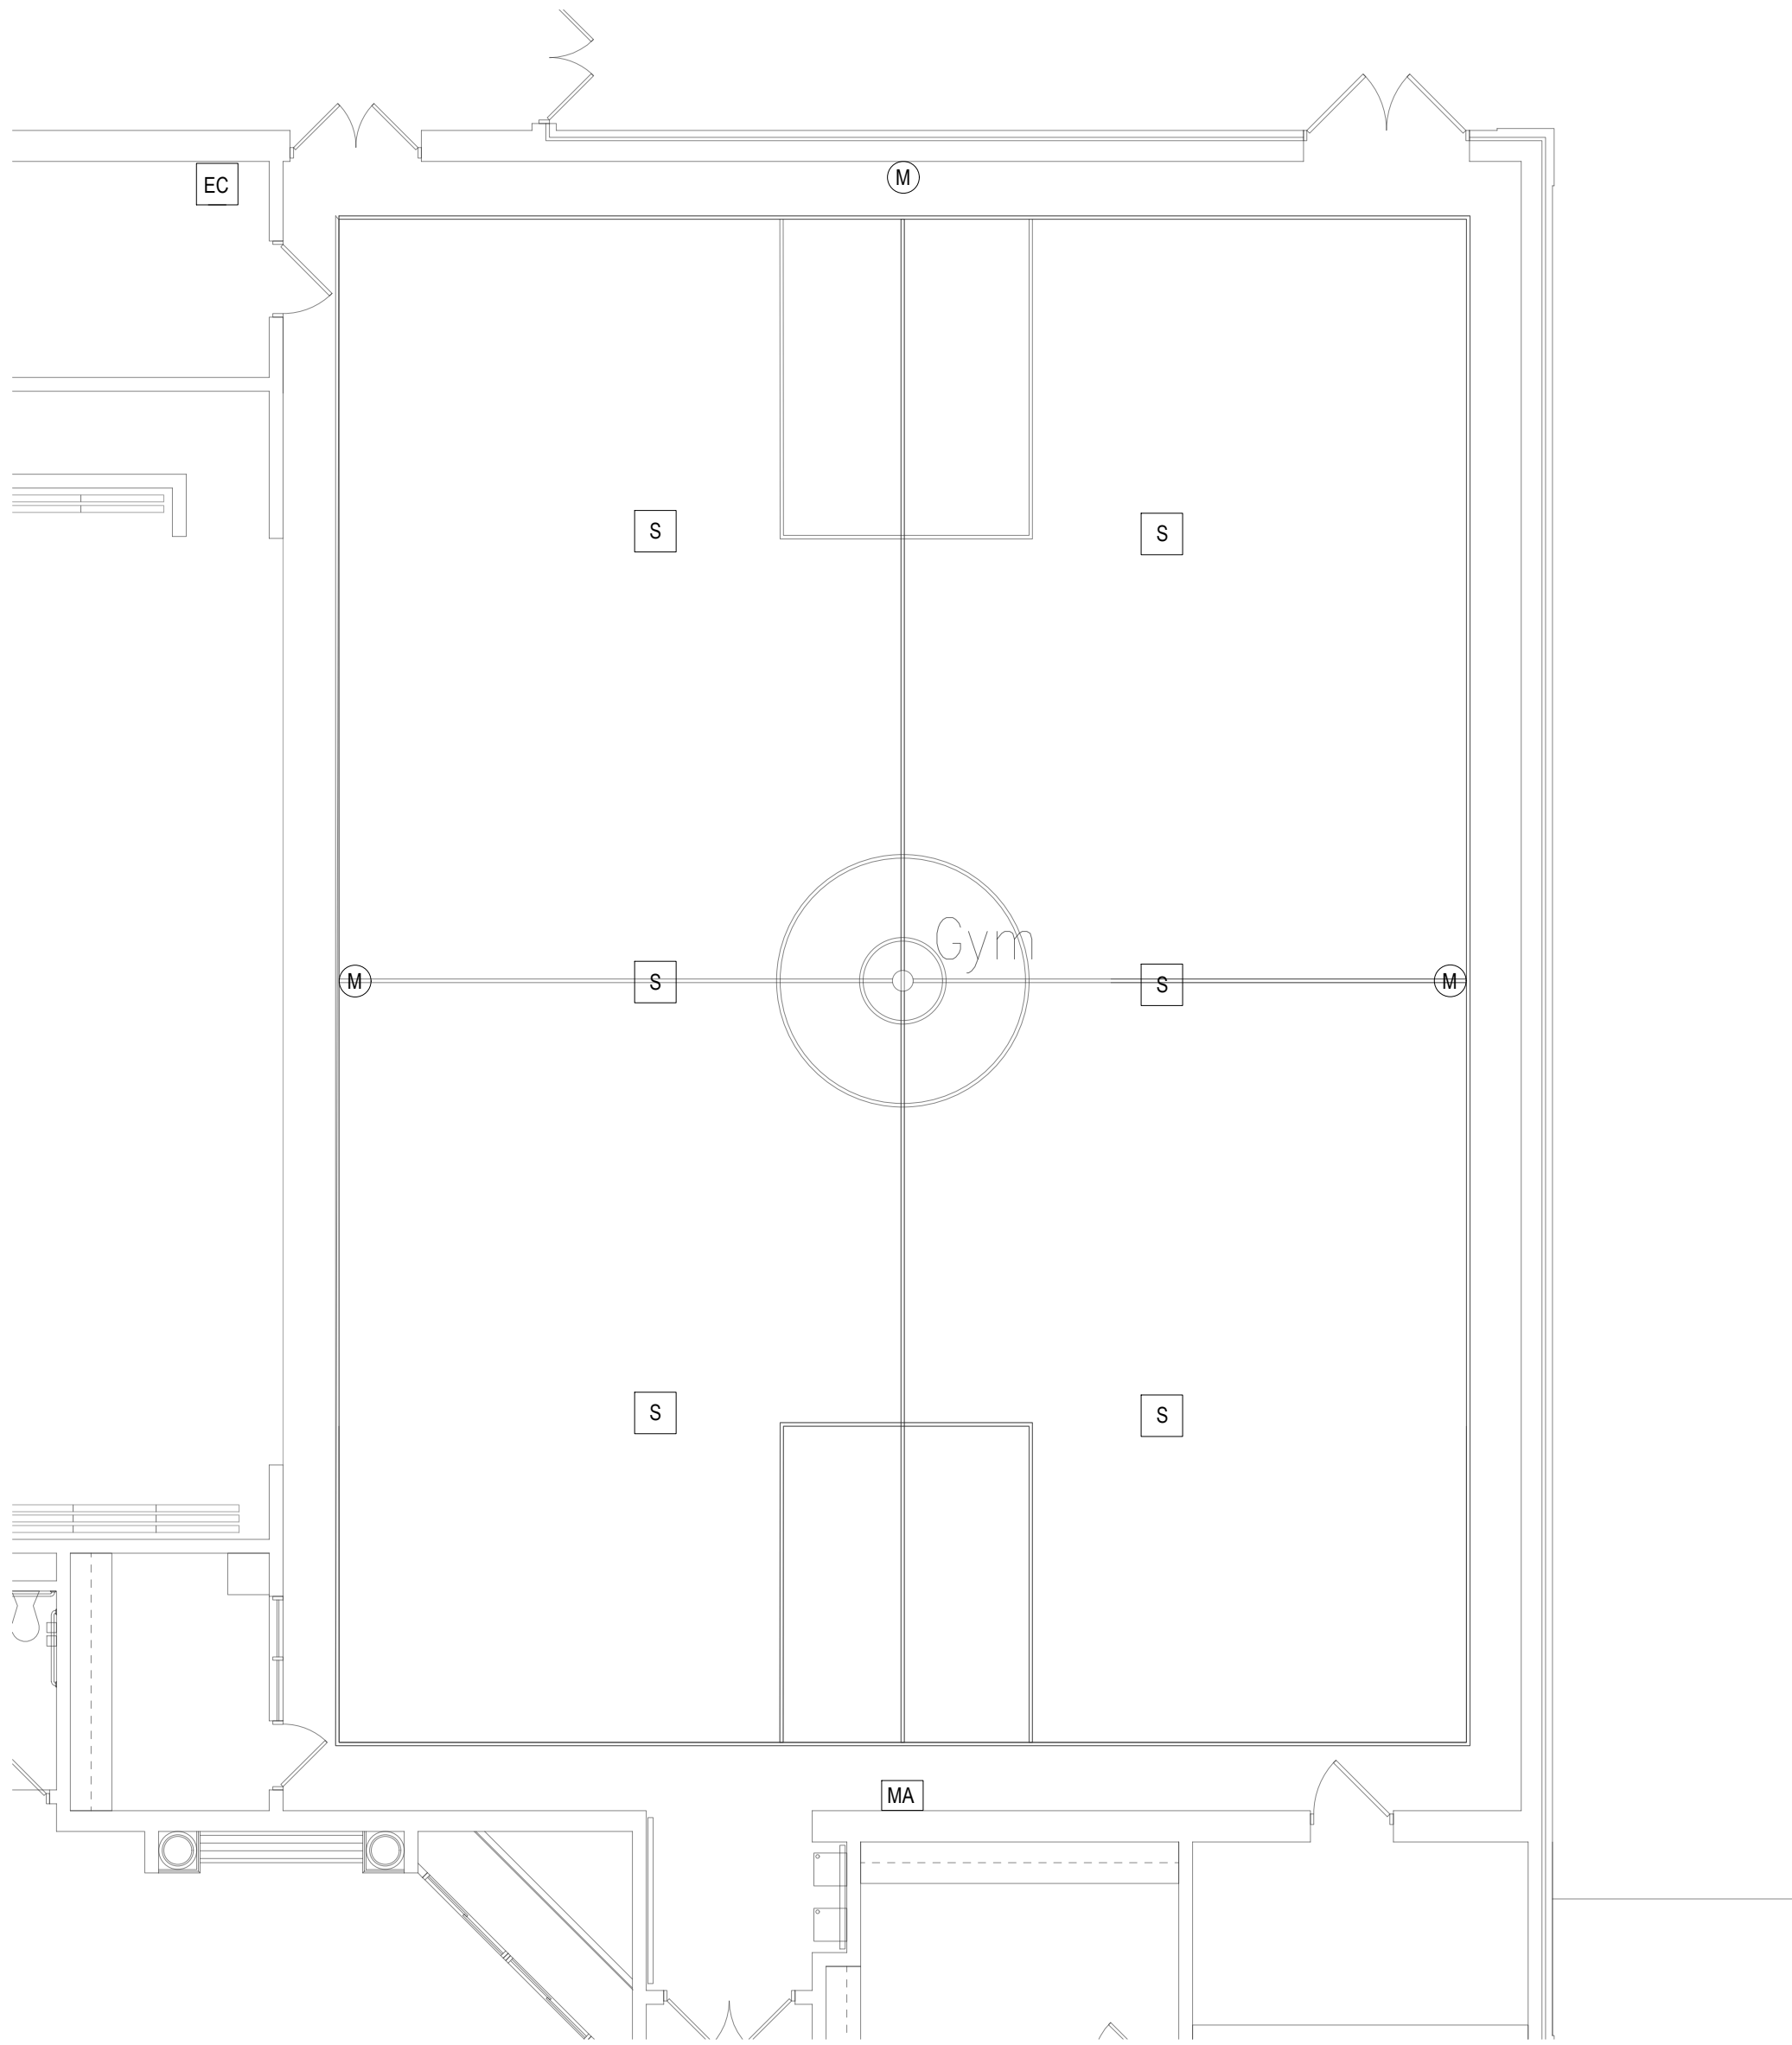


1 GYMNASIUM AUDIO VIDEO SYSTEMS
1/8" = 1'-0"

GENERAL AUDIO VIDEO NOTES:

1. FINAL LOCATIONS TO BE FIELD VERIFIED WITH OWNER PRIOR TO INSTALLATION.
2. PROVIDE SAFETY CABLES FOR ALL SPEAKERS.

AUDIO VIDEO FLOOR PLAN SYMBOL LEGEND:

- EC EQUIPMENT CABINET
S SPEAKER
M MICROPHONE
MA MIC/AUX INPUT

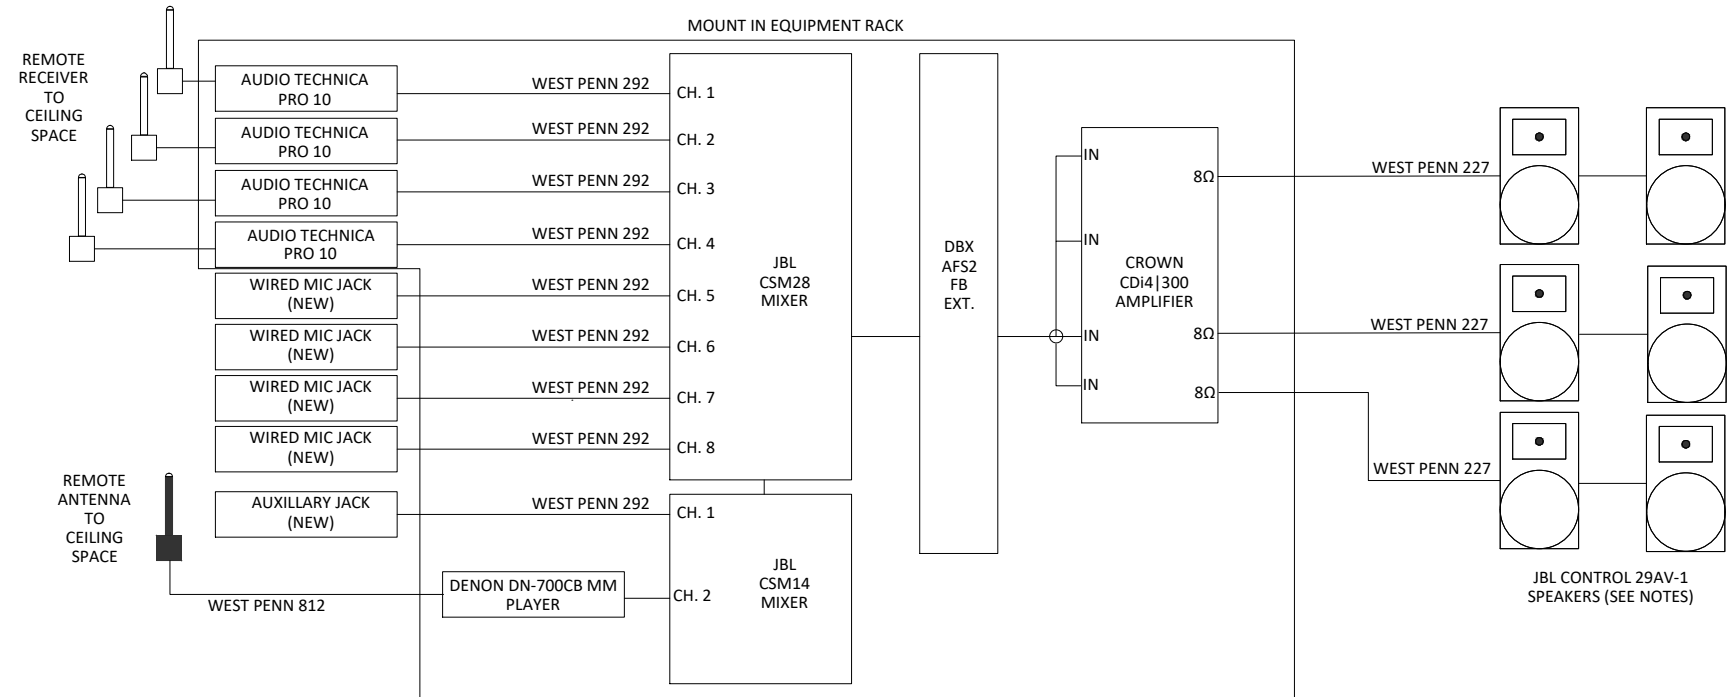

1. AT MORRIS ELEMENTARY - REUSE EXISTING SIX SPEAKERS.
2. AT RIDGEWOOD, WINCHESTER AND SILVER SPRINGS ELEMENTARY - ADD TWO (2) SPEAKERS TO EXISTING. VERIFY EXISTING SPEAKER TYPE PRIOR TO ORDERING. ASSUME JBL CONTROL 29AV-1 FOR BID PURPOSES.
3. AT THORNTON CREEK - REMOVE EXISTING ANTIQUE SPEAKERS.
4. AT COOKE SCHOOL - REUSE EXISTING SIX SPEAKERS.





1 CAFETERIA AUDIO VIDEO SYSTEM
1/8" = 1'-0"

GENERAL AUDIO VIDEO NOTES:

- FINAL LOCATIONS TO BE FIELD VERIFIED WITH OWNER PRIOR TO INSTALLATION.
- PROVIDE SAFETY CABLES FOR ALL SPEAKERS.

AUDIO VIDEO FLOOR PLAN SYMBOL LEGEND:

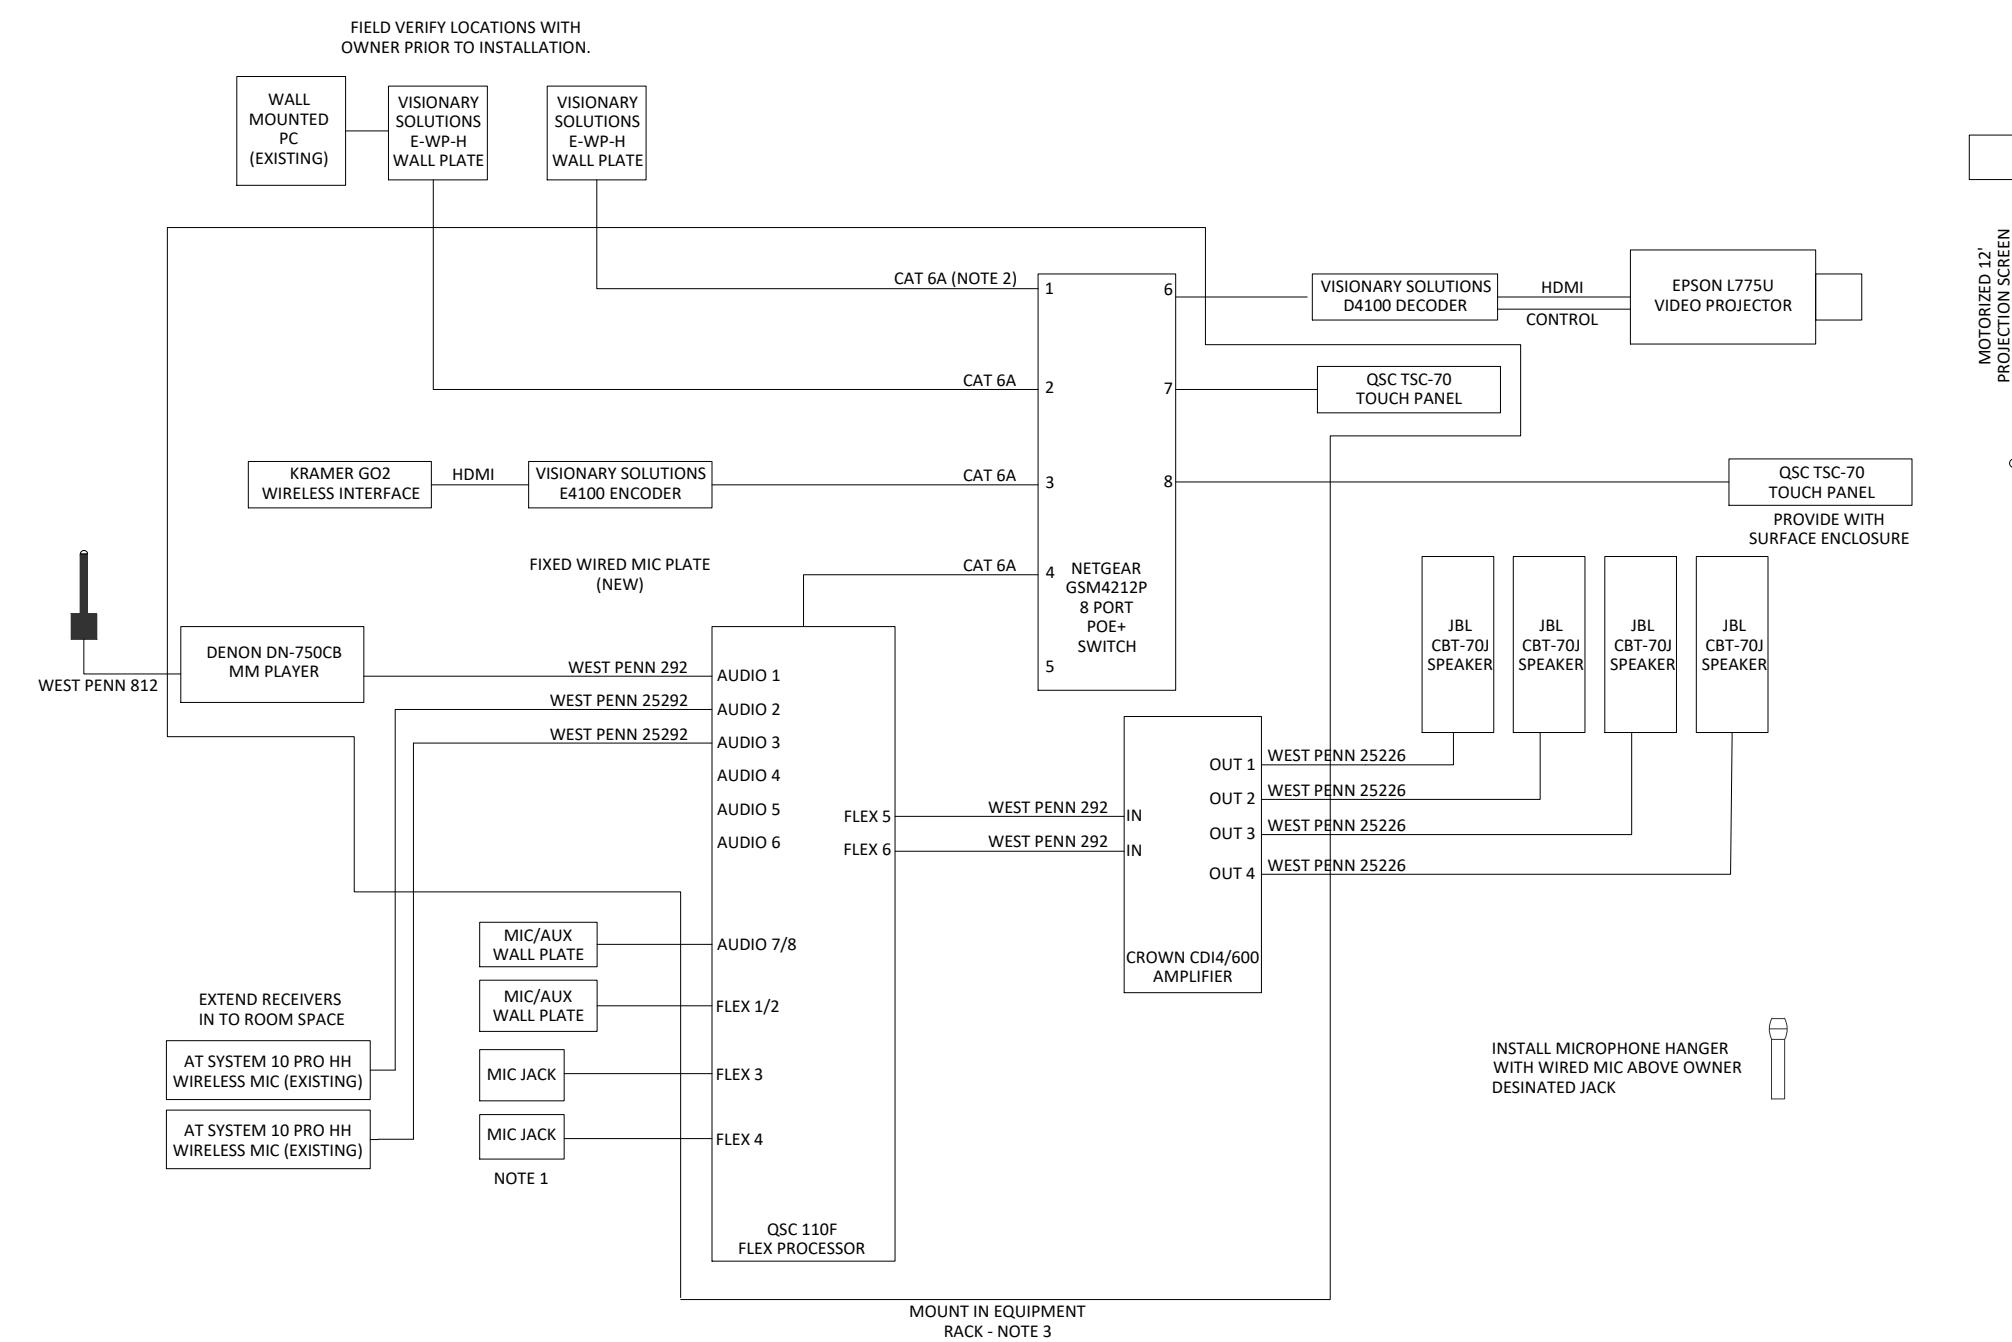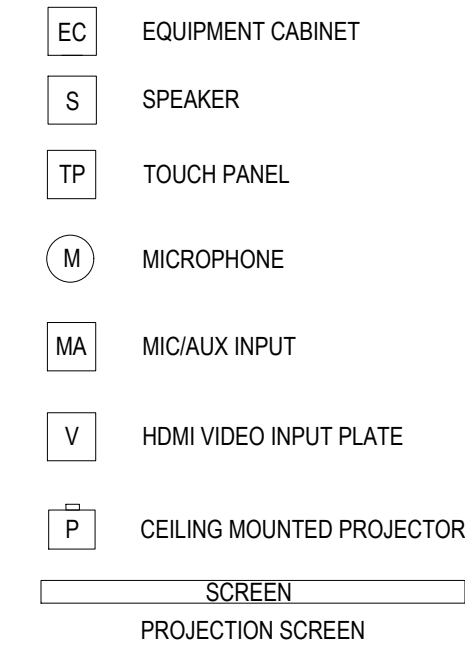

NOTE 1 - NUMBER OF MIC JACKS PER ROOM MAY DIFFER. SEE PLANS. ALL JACKS ARE TO BE REWIRED WITH WEST PENN 25202.
NOTE 2 - ALL CAT6A CABLES SHALL BE SHIELDED AND PLENUM RATED. PROVIDE SHIELDED CONNECTORS FOR ALL CONNECTIONS
NOTE 3 - REMOVE EXISTING RACK. REUSE EXISTING AUDIO TECHNICA SYSTEM 10 PRO WIRELESS MICROPHONES

2 CAFETERIA AUDIO VIDEO SCHEMATIC
NTS

KEY PLAN

OWNER

Northville Public
Schools

PROJECT NAME

Audio and Video Systems

Northville, MI 48167

PROJECT NO.

25-NPS-AVS-01

ISSUES / REVISIONS

03.12.2025 BIDS

DRAWN BY

BMJ

CHECKED BY

BG

APPROVED BY


SJB

SHEET NAME

SILVER SPRINGS
ELEMENTARY
CAFETERIA AVS

SHEET NO.

TA106

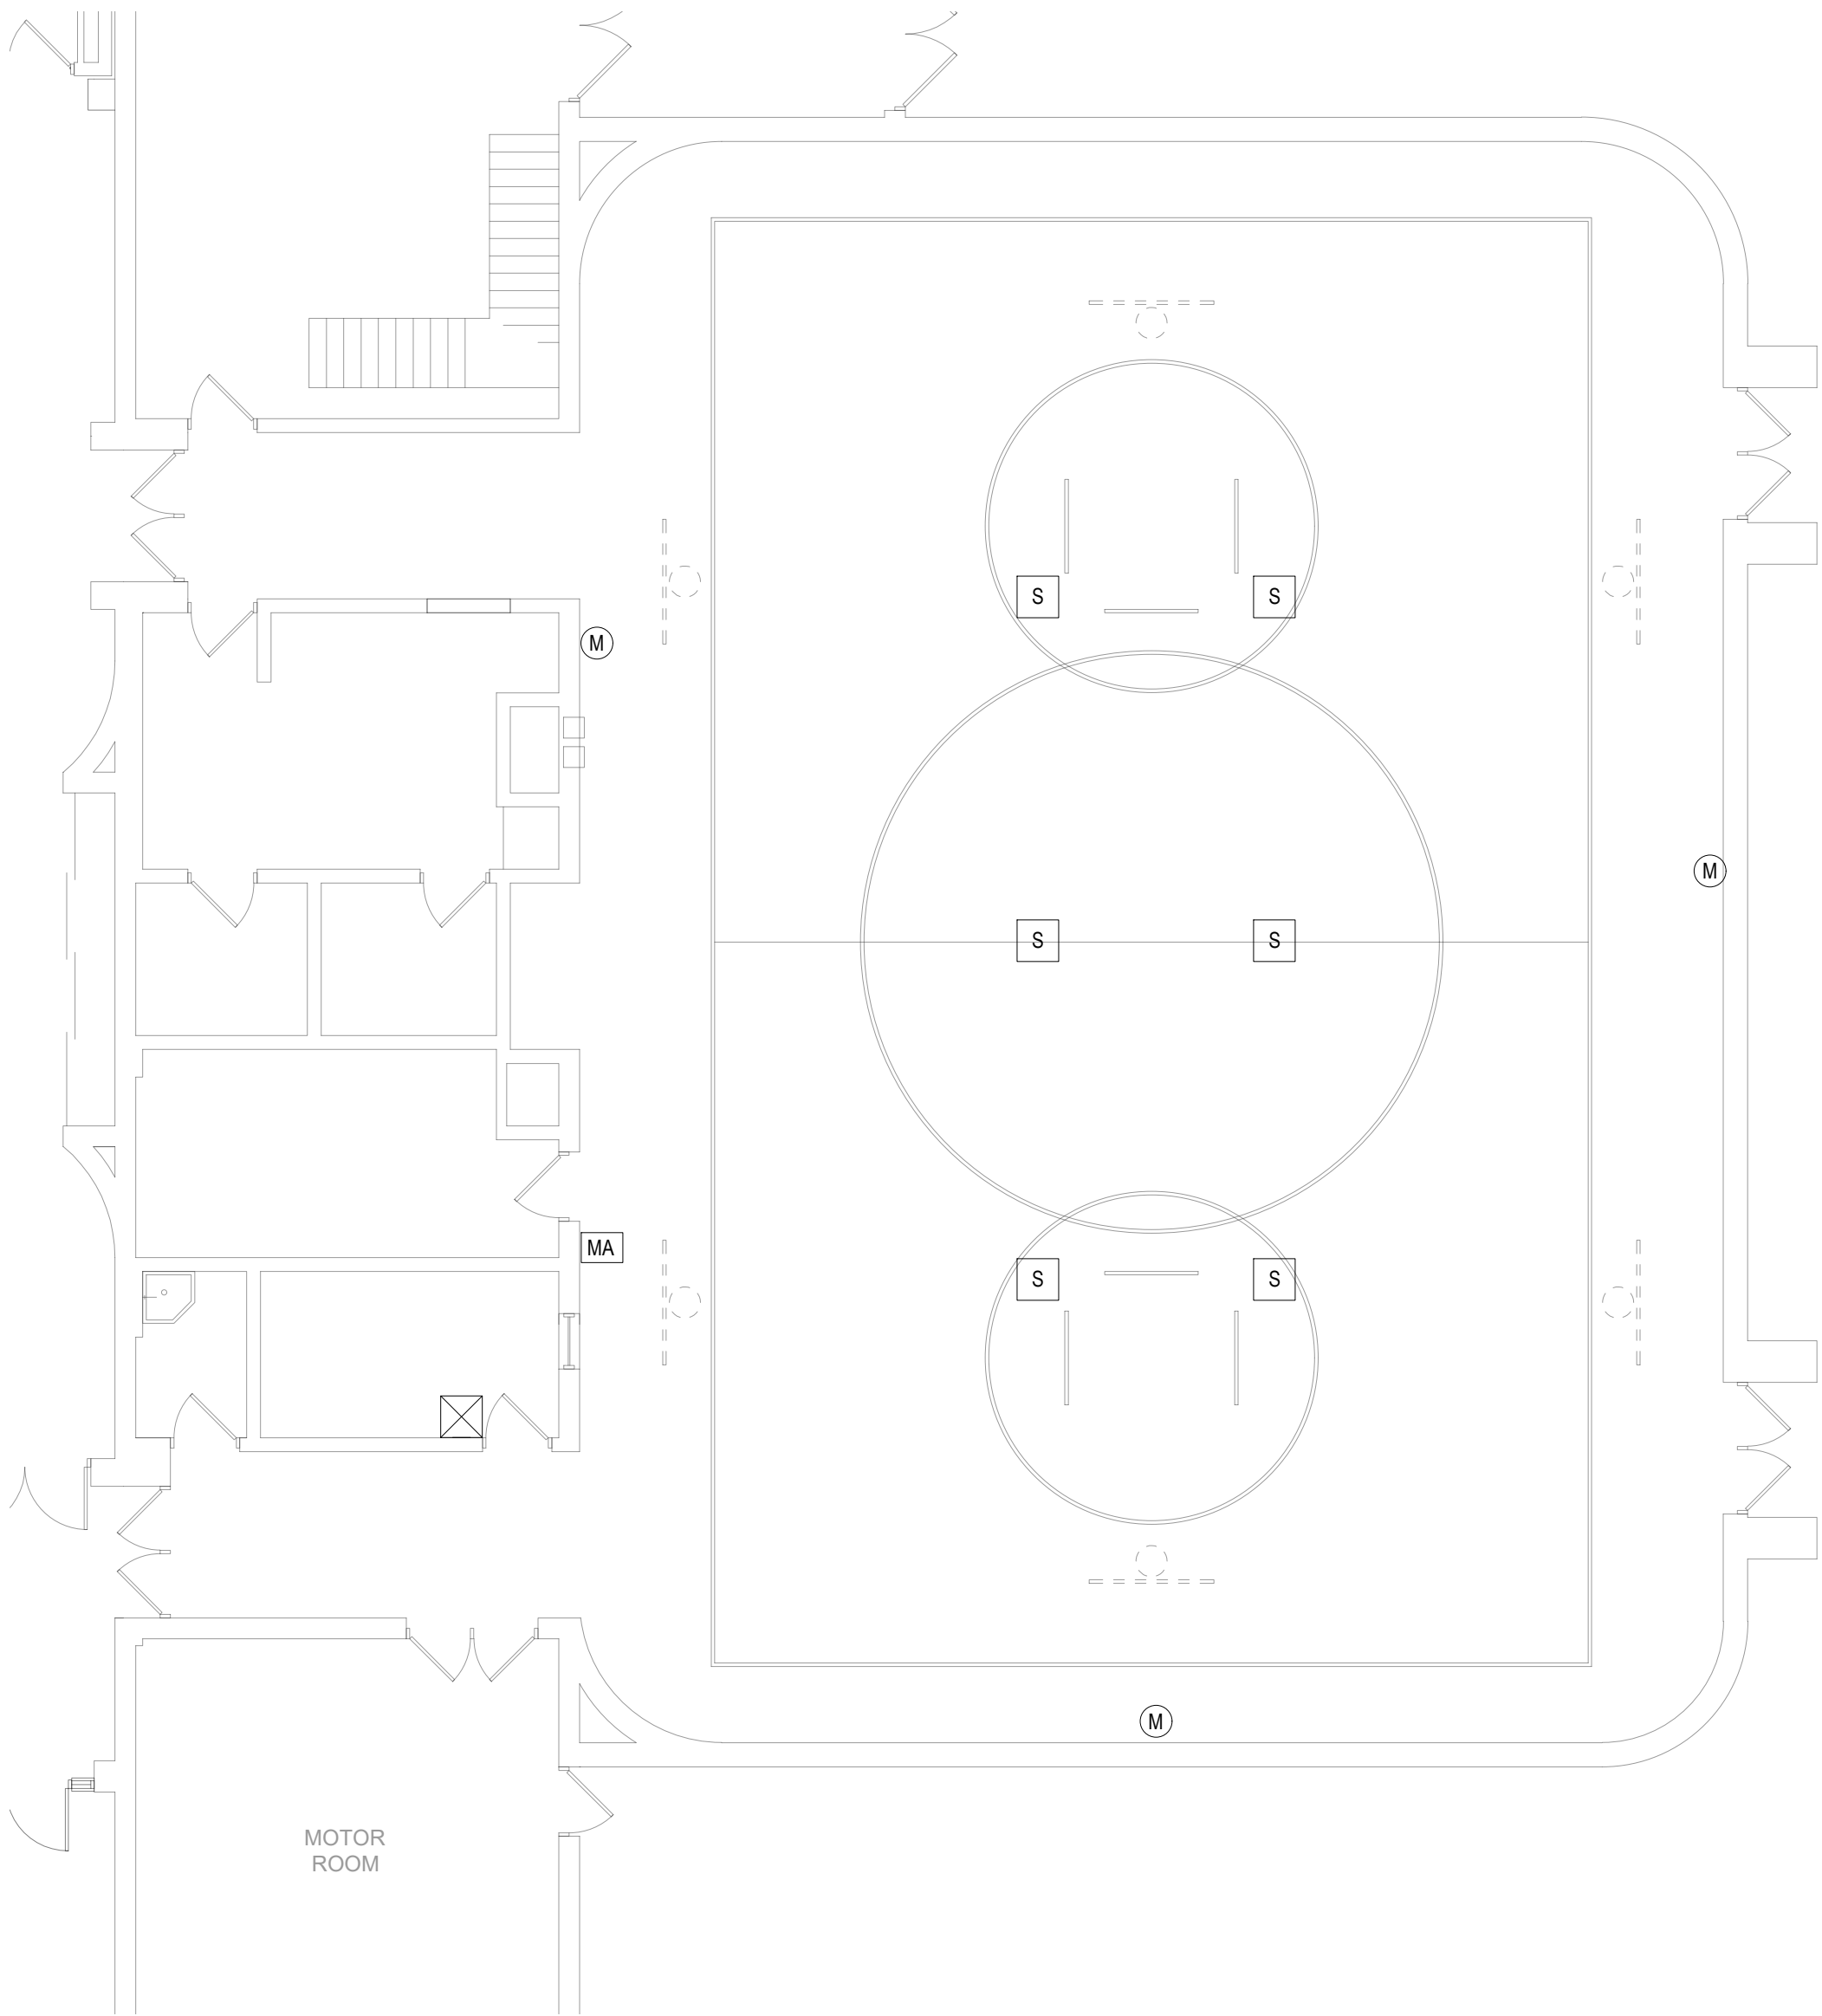


1 GYMNASIUM AUDIO VIDEO SYSTEM
1/8" = 1'-0"

- GENERAL AUDIO VIDEO NOTES:
1. FINAL LOCATIONS TO BE FIELD VERIFIED WITH OWNER PRIOR TO INSTALLATION.
 2. PROVIDE SAFETY CABLES FOR ALL SPEAKERS.

AUDIO VIDEO FLOOR PLAN SYMBOL LEGEND:

- EC EQUIPMENT CABINET
S SPEAKER
M MICROPHONE
MA MIC/AUX INPUT

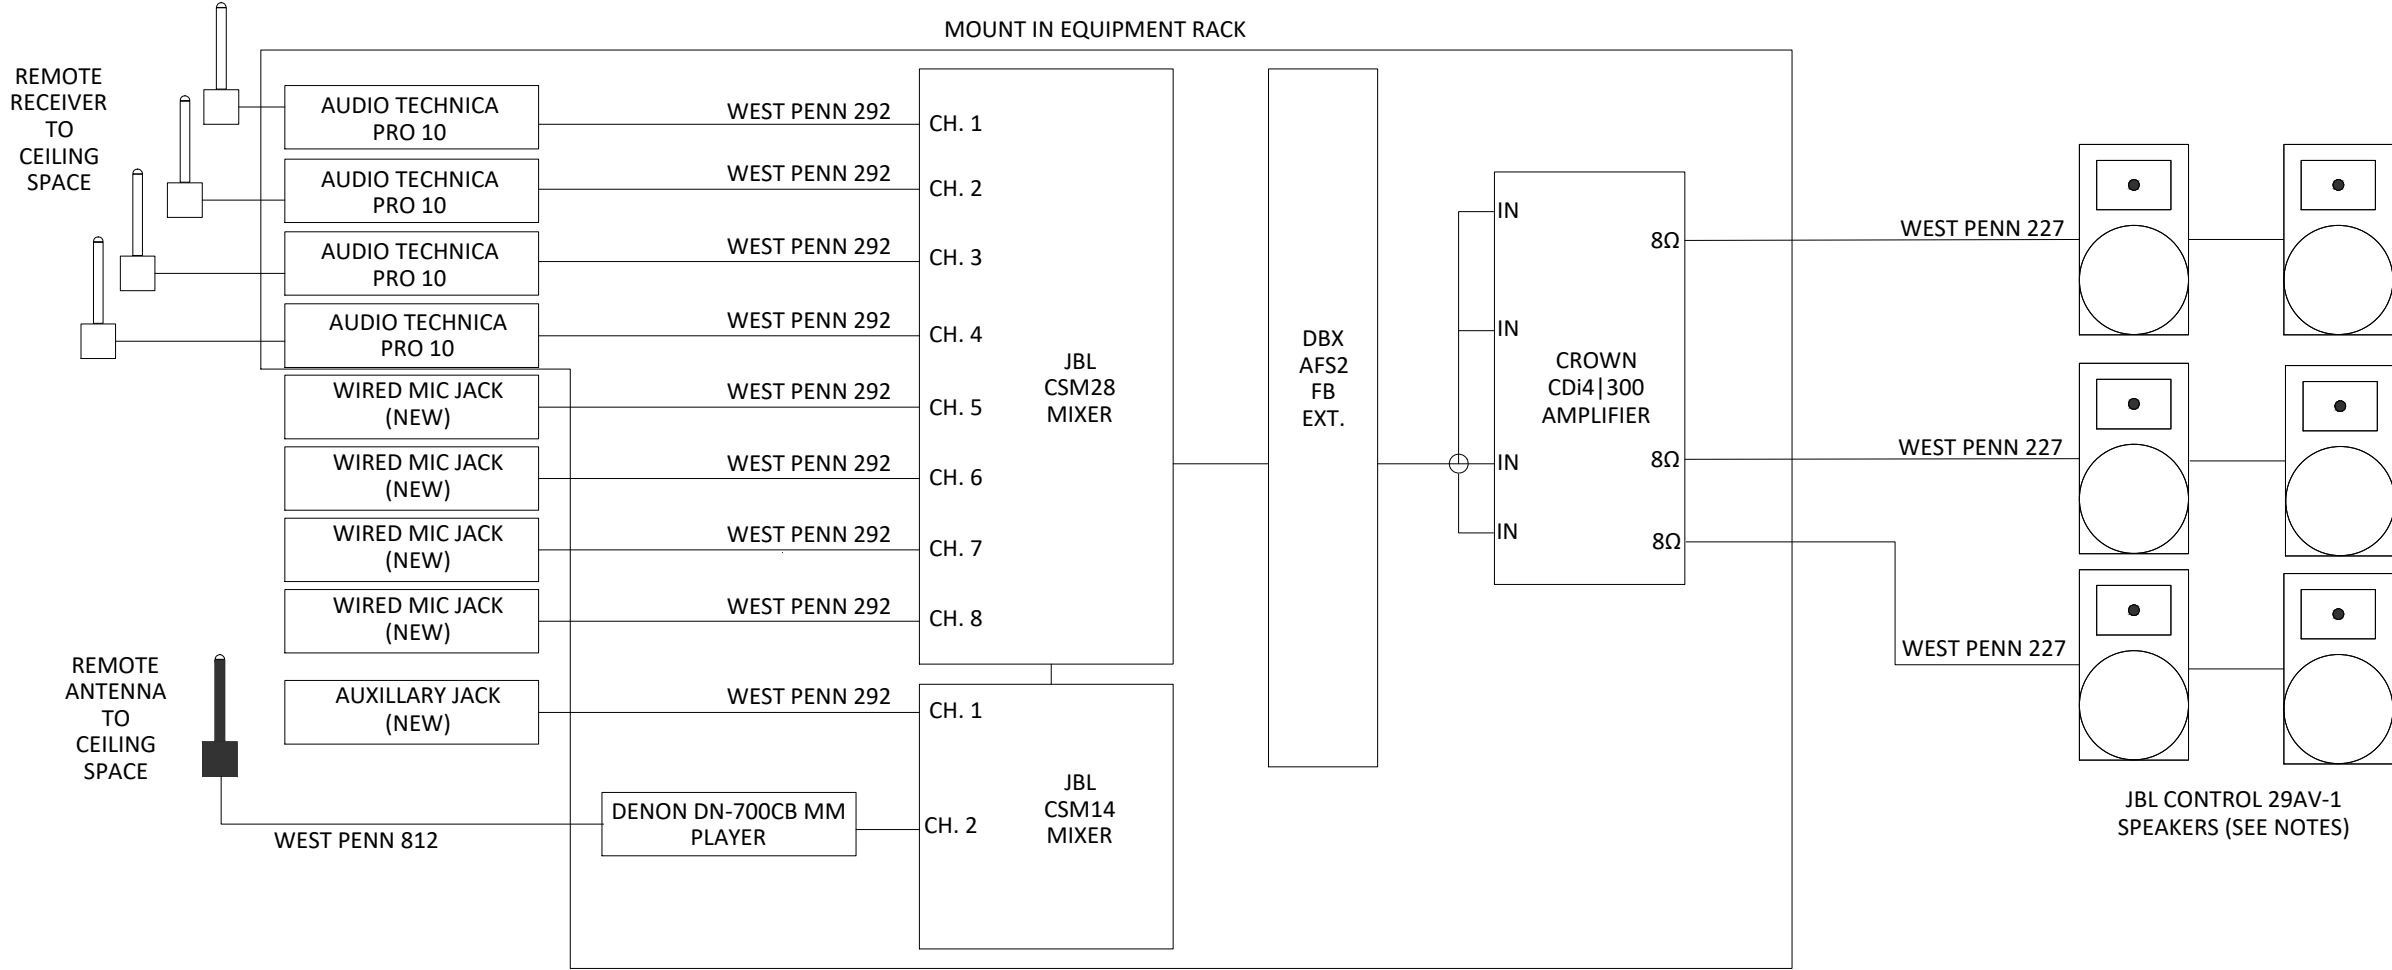

1. AT MORaine ELEMENTARY - REUSE EXISTING SIX SPEAKERS.
2. AT RIDGEWOOD, WINCHESTER AND SILVER SPRINGS ELEMENTARY - ADD TWO (2) SPEAKERS TO EXISTING. VERIFY EXISTING SPEAKER TYPE PRIOR TO ORDERING. ASSUME JBL CONTROL 29AV-1 FOR BID PURPOSES.
3. AT THORNTON CREEK - REMOVE EXISTING ANTIQUE SPEAKERS.
4. AT COOKE SCHOOL - REUSE EXISTING SIX SPEAKERS.

KEY PLAN

OWNER
Northville Public
Schools

PROJECT NAME
Audio and Video Systems

Northville, MI 48167

PROJECT NO.
25-NPS-AVS-01

ISSUES / REVISIONS
03.12.2025 BIDS

DRAWN BY
BMJ
CHECKED BY
BG
APPROVED BY
SJB

SHEET NAME
SILVER SPRINGS
ELEMENTARY GYM
AVS

SHEET NO.
TA107



OWNER

PROJECT NAME

Audio and Video Systems

Northville, MI 48167

PROJECT NO.

ISSUES / REVISIONS

03.12.2025 BIDS

DRAWN BY

BMJ


CHECKED BY _____

APPROVED BY _____

SHEET NAME

SHEET NO.

 
TA108




GENERAL AUDIO VIDEO NOTES:

1. FINAL LOCATIONS TO BE FIELD VERIFIED WITH OWNER PRIOR TO INSTALLATION
2. PROVIDE SAFETY CABLES FOR ALL SPEAKERS.

AUDIO VIDEO FLOOR PLAN SYMBOL LEGEND:

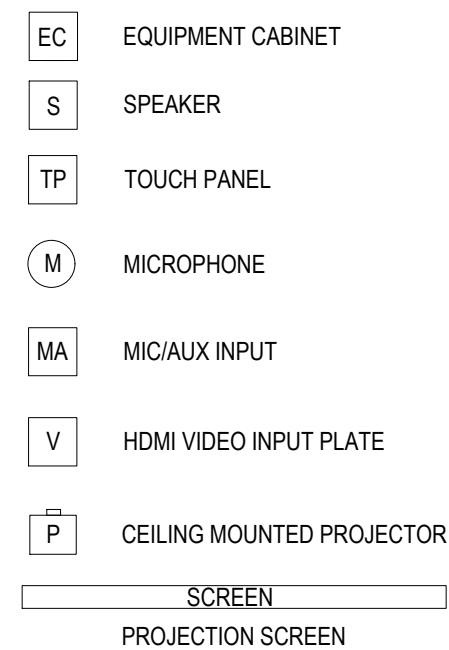

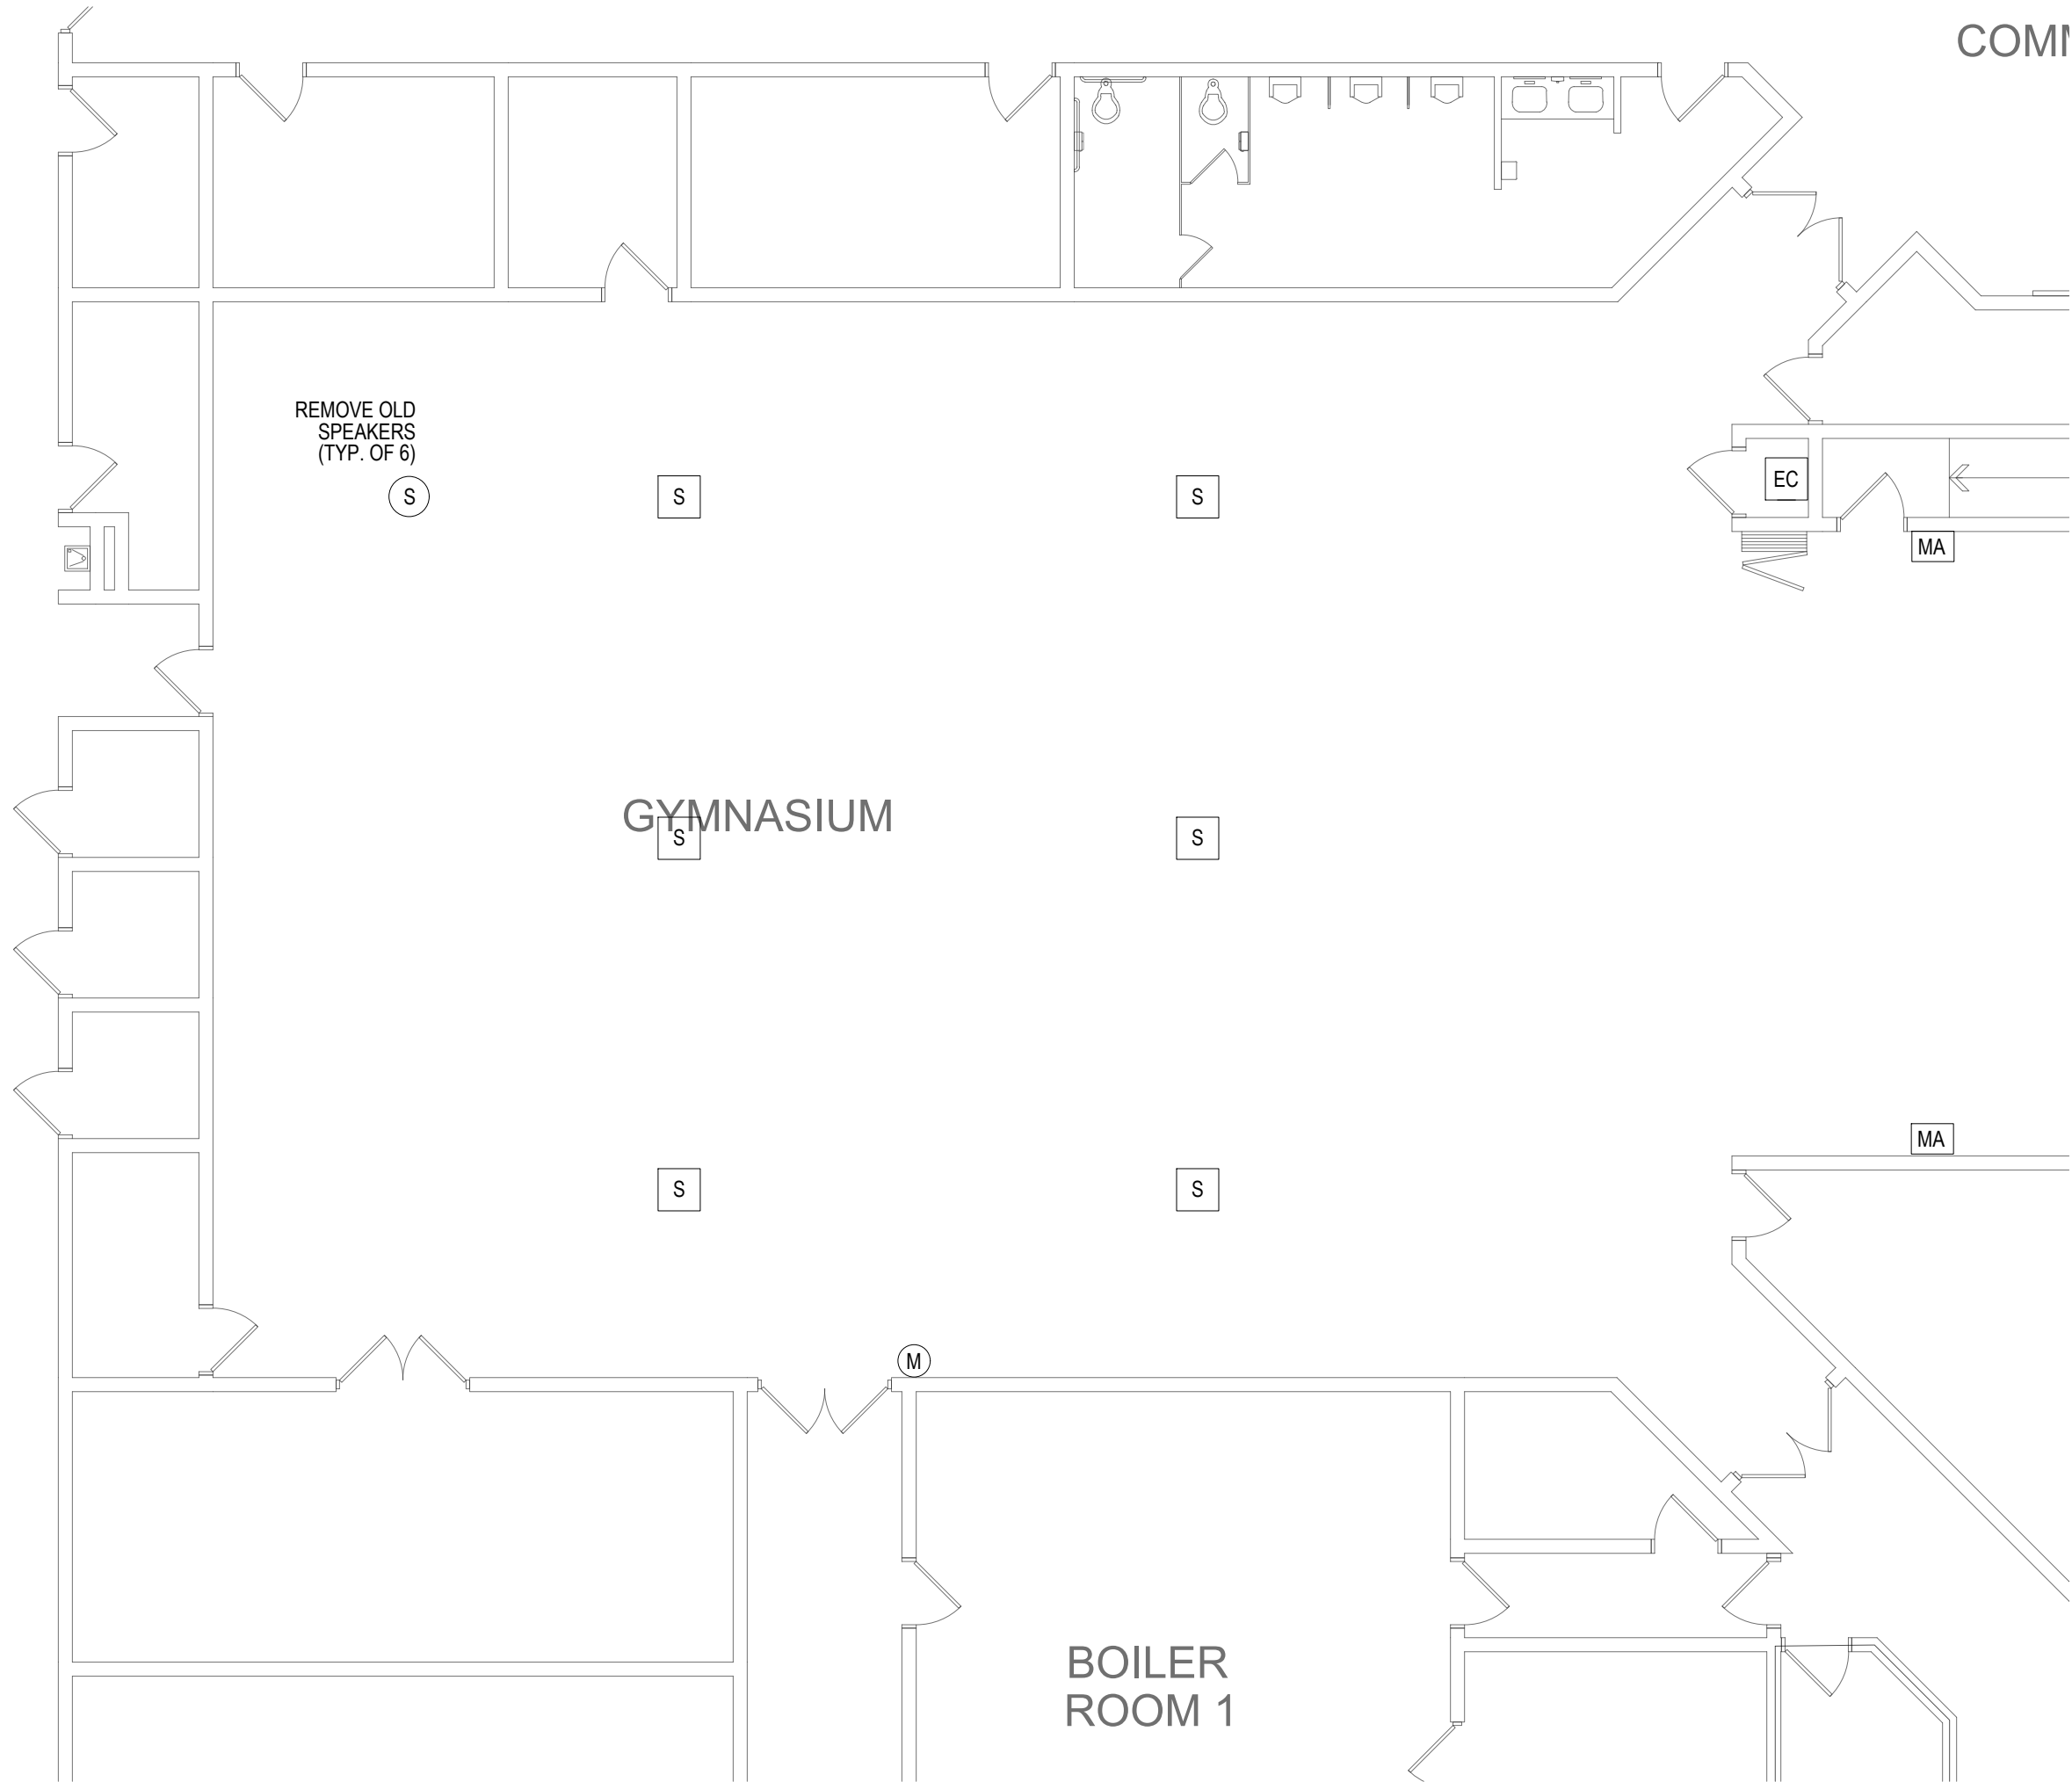


1 GYMNASIUM AUDIO VIDEO SYSTEM
3/64" = 1'-0"

GENERAL AUDIO VIDEO NOTES:

1. FINAL LOCATIONS TO BE FIELD VERIFIED WITH OWNER PRIOR TO INSTALLATION.
2. PROVIDE SAFETY CABLES FOR ALL SPEAKERS.

AUDIO VIDEO FLOOR PLAN SYMBOL LEGEND:

- EC EQUIPMENT CABINET
- S SPEAKER
- M MICROPHONE
- MA MIC/AUX INPUT

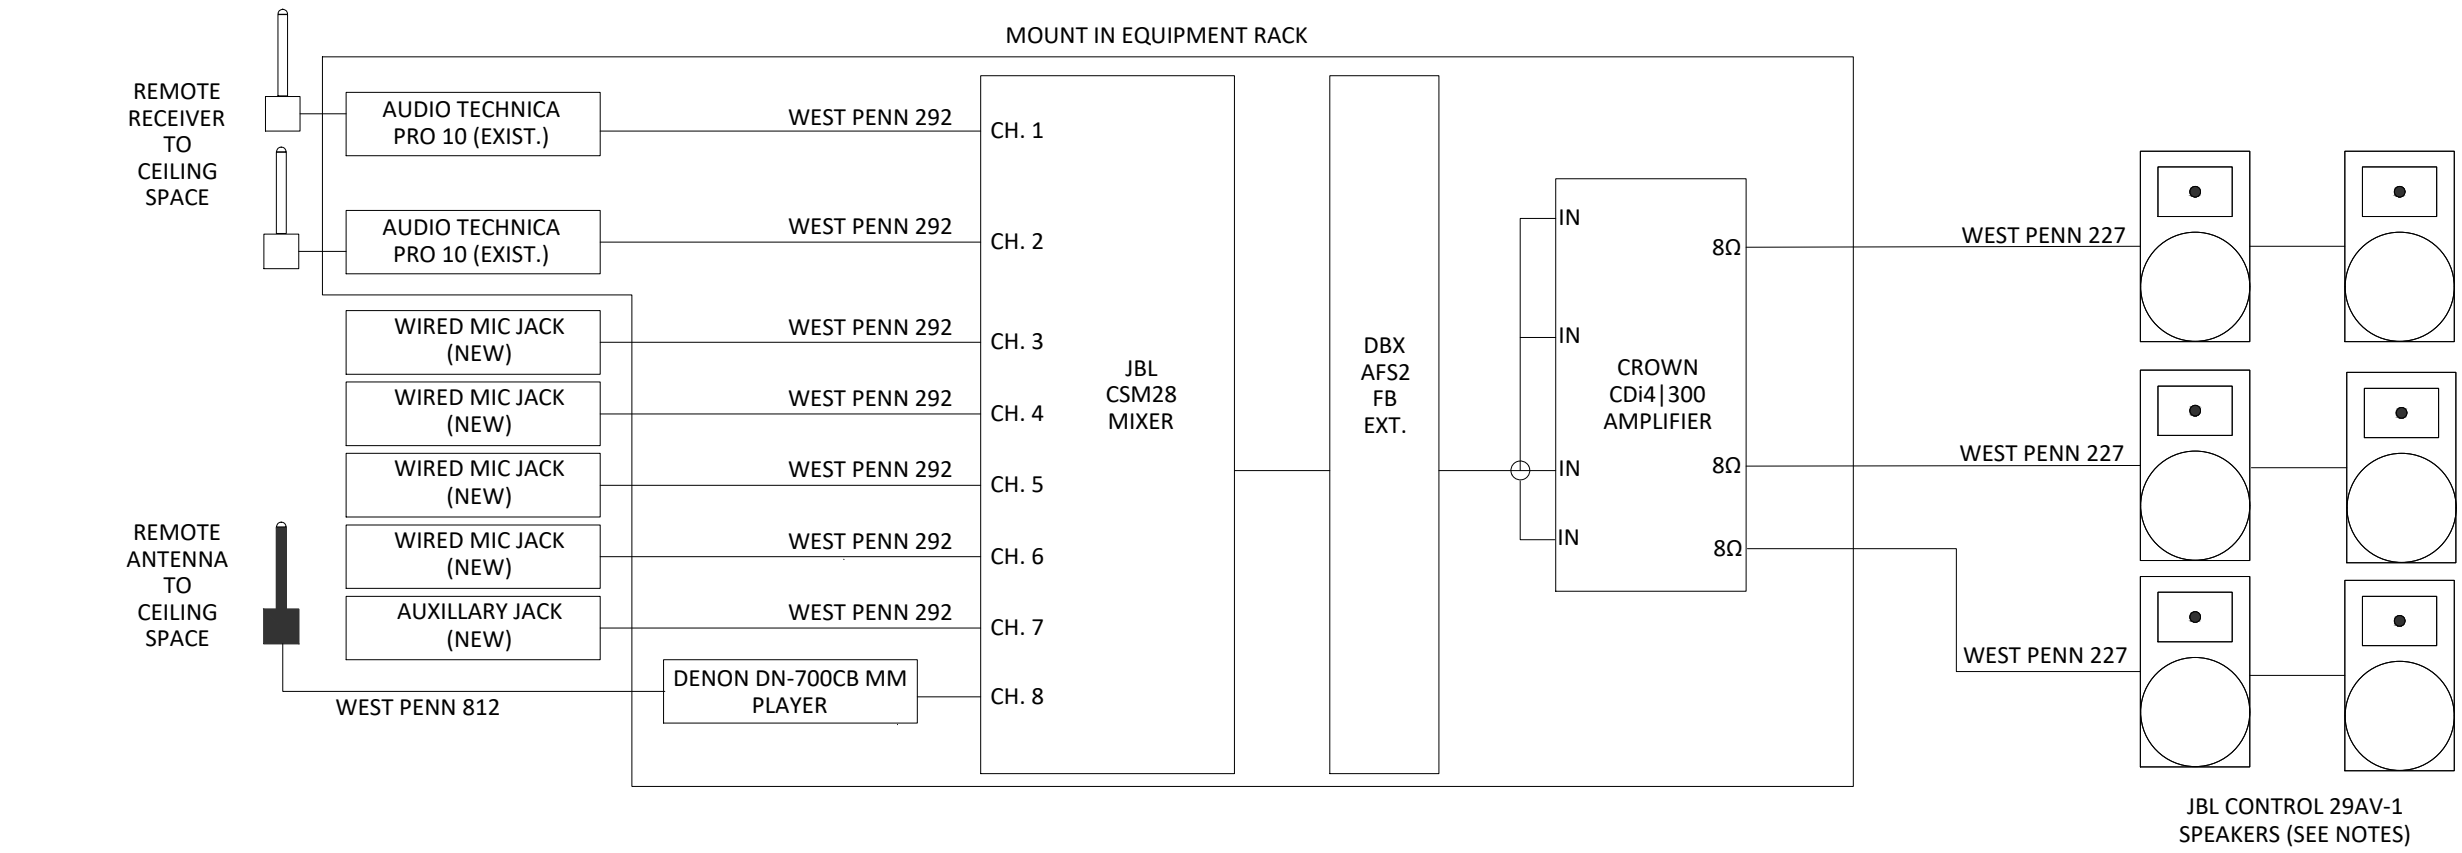


1. AT MORaine ELEMENTARY - REUSE EXISTING SIX SPEAKERS.
2. AT RIDGEWOOD, WINCHESTER AND SILVER SPRINGS ELEMENTARY - ADD TWO (2) SPEAKERS TO EXISTING. VERIFY EXISTING SPEAKER TYPE PRIOR TO ORDERING. ASSUME JBL CONTROL 29AV-1 FOR BID PURPOSES.
3. AT THORNTON CREEK - REMOVE EXISTING ANTIQUE SPEAKERS.
4. AT COOKE SCHOOL - REUSE EXISTING SIX SPEAKERS.

GENERAL AUDIO VIDEO NOTES:


1. FINAL LOCATIONS TO BE FIELD VERIFIED WITH OWNER PRIOR TO INSTALLATION.
2. PROVIDE SAFETY CABLES FOR ALL SPEAKERS.

AUDIO VIDEO FLOOR PLAN SYMBOL LEGEND:

EC	EQUIPMENT CABINET
S	SPEAKER
TP	TOUCH PANEL
M	MICROPHONE
MA	MIC/AUX INPUT
V	HDMI VIDEO INPUT PLATE
P	CEILING MOUNTED PROJECTOR
SCREEN	SCREEN
PROJECTION SCREEN	PROJECTION SCREEN

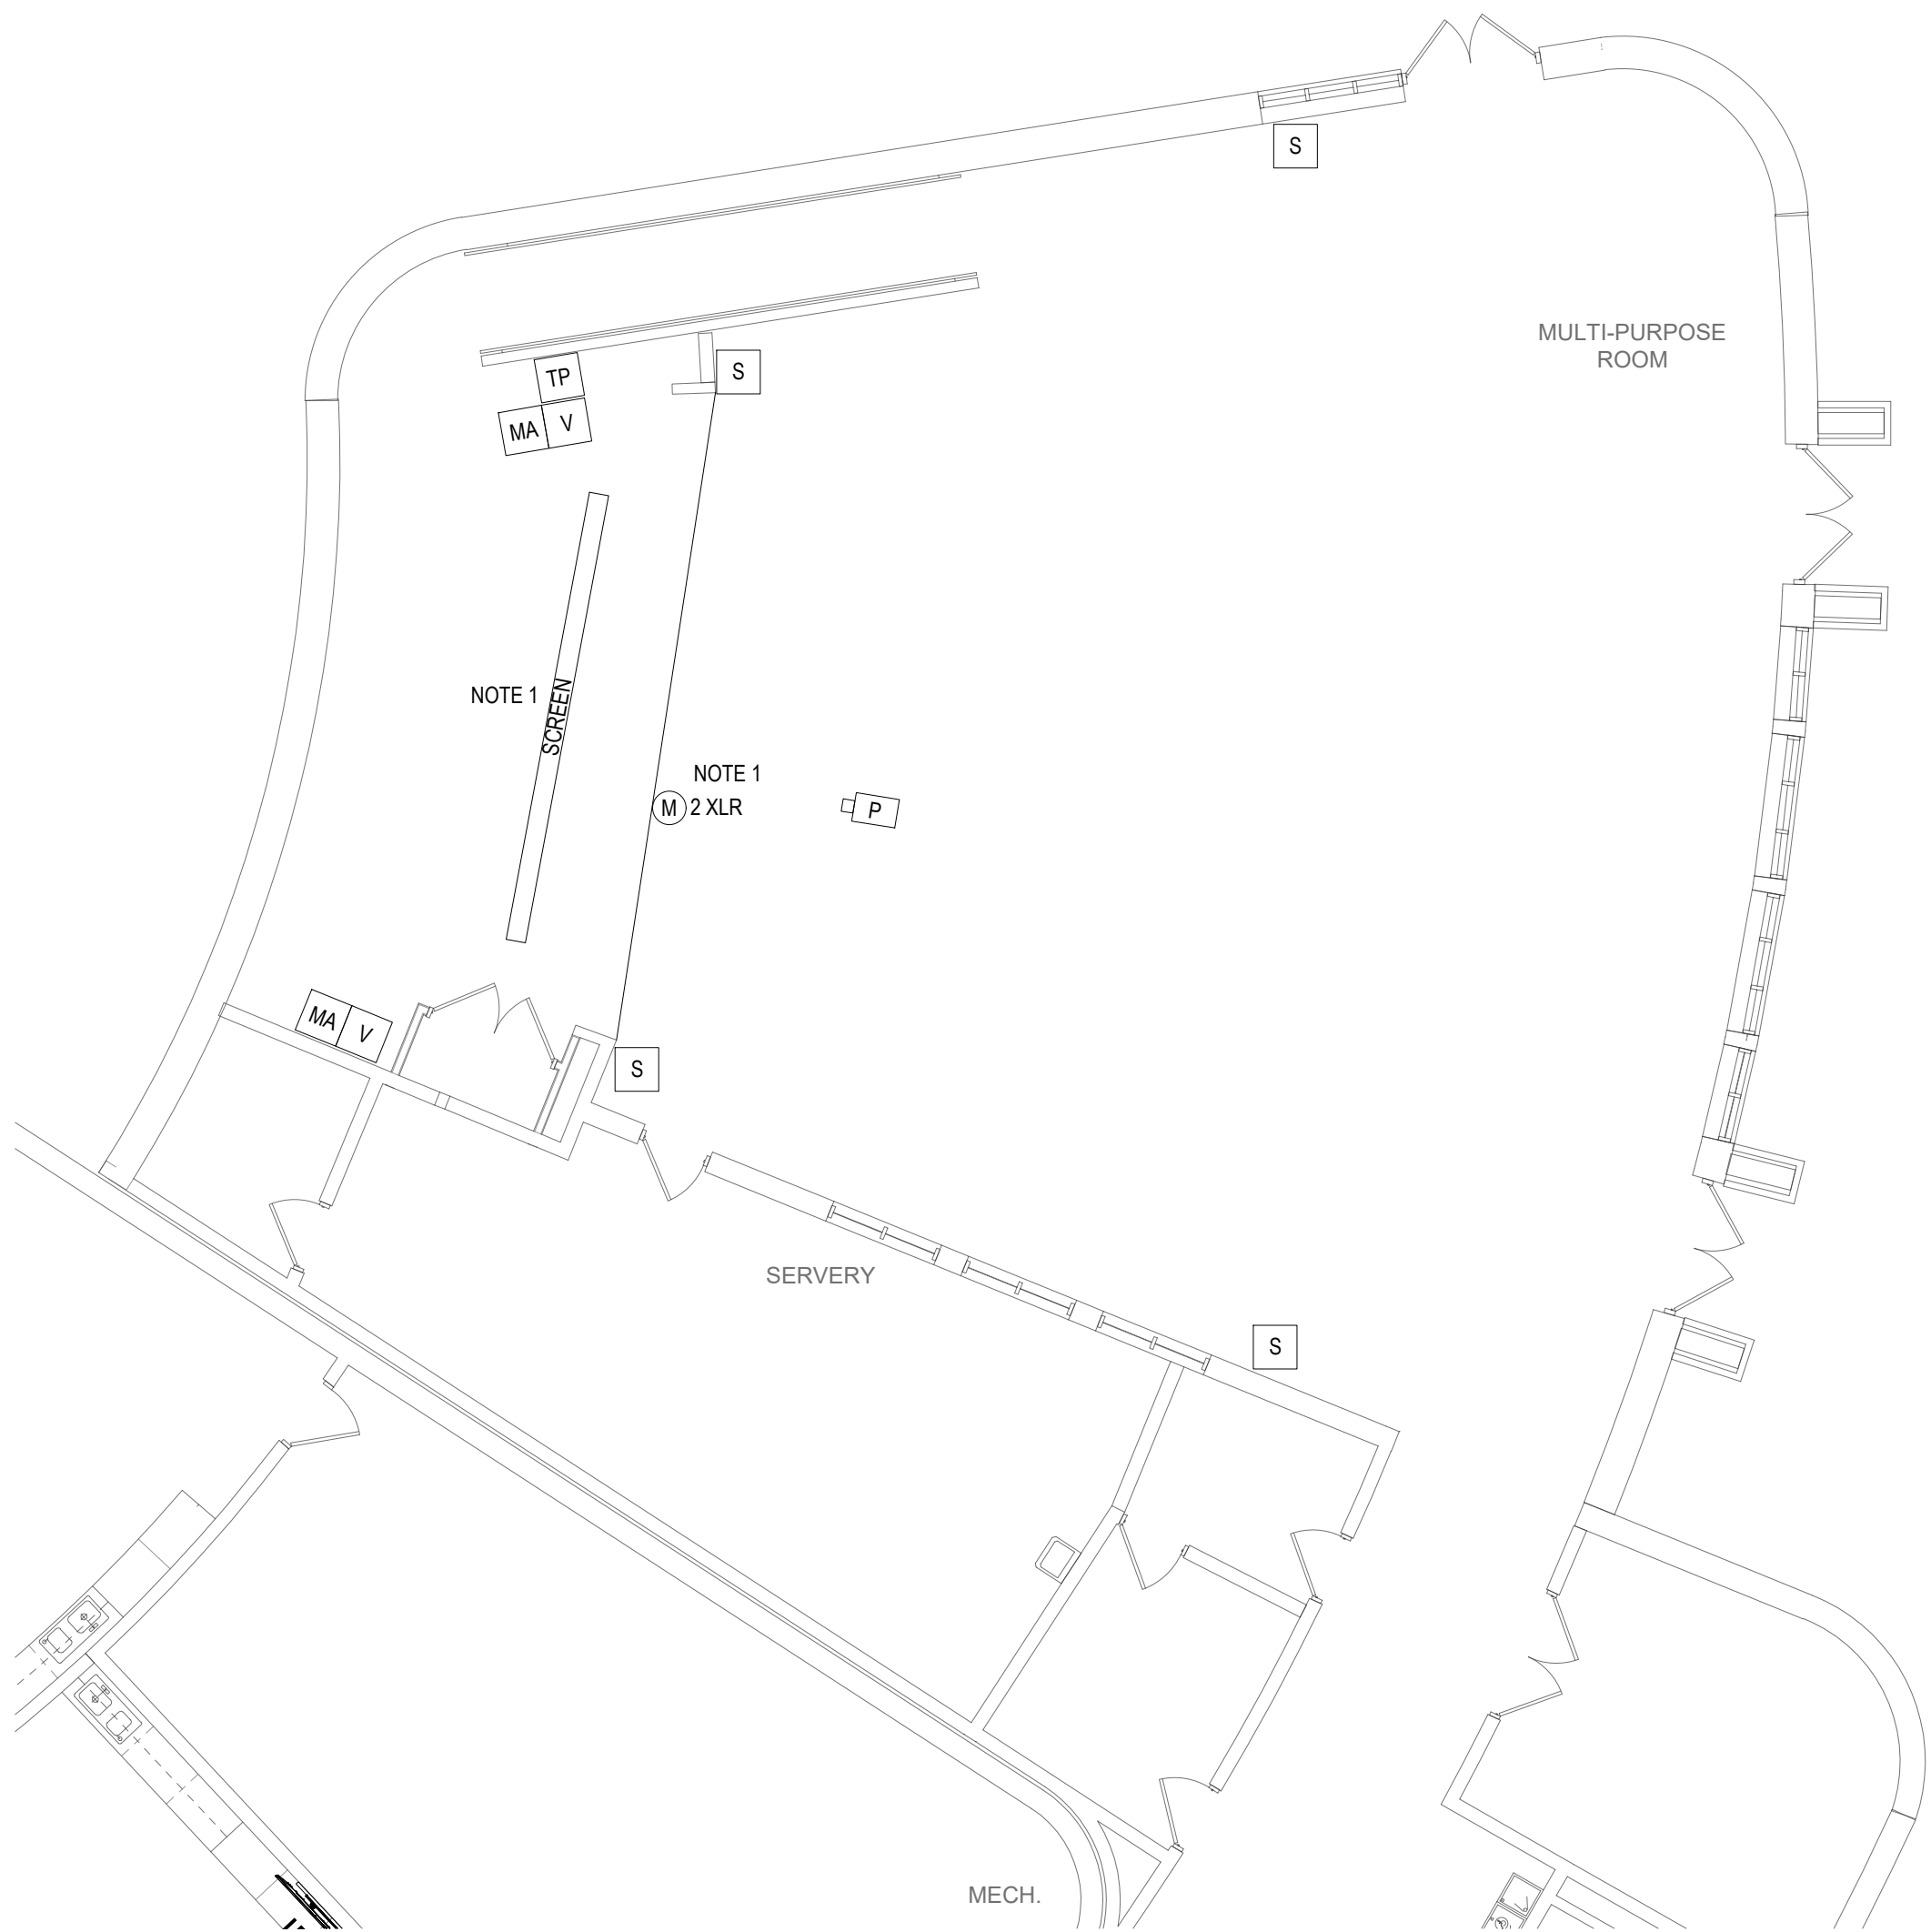

1 CAFETERIA AUDIO VIDEO SYSTEM
1/8" = 1'-0"

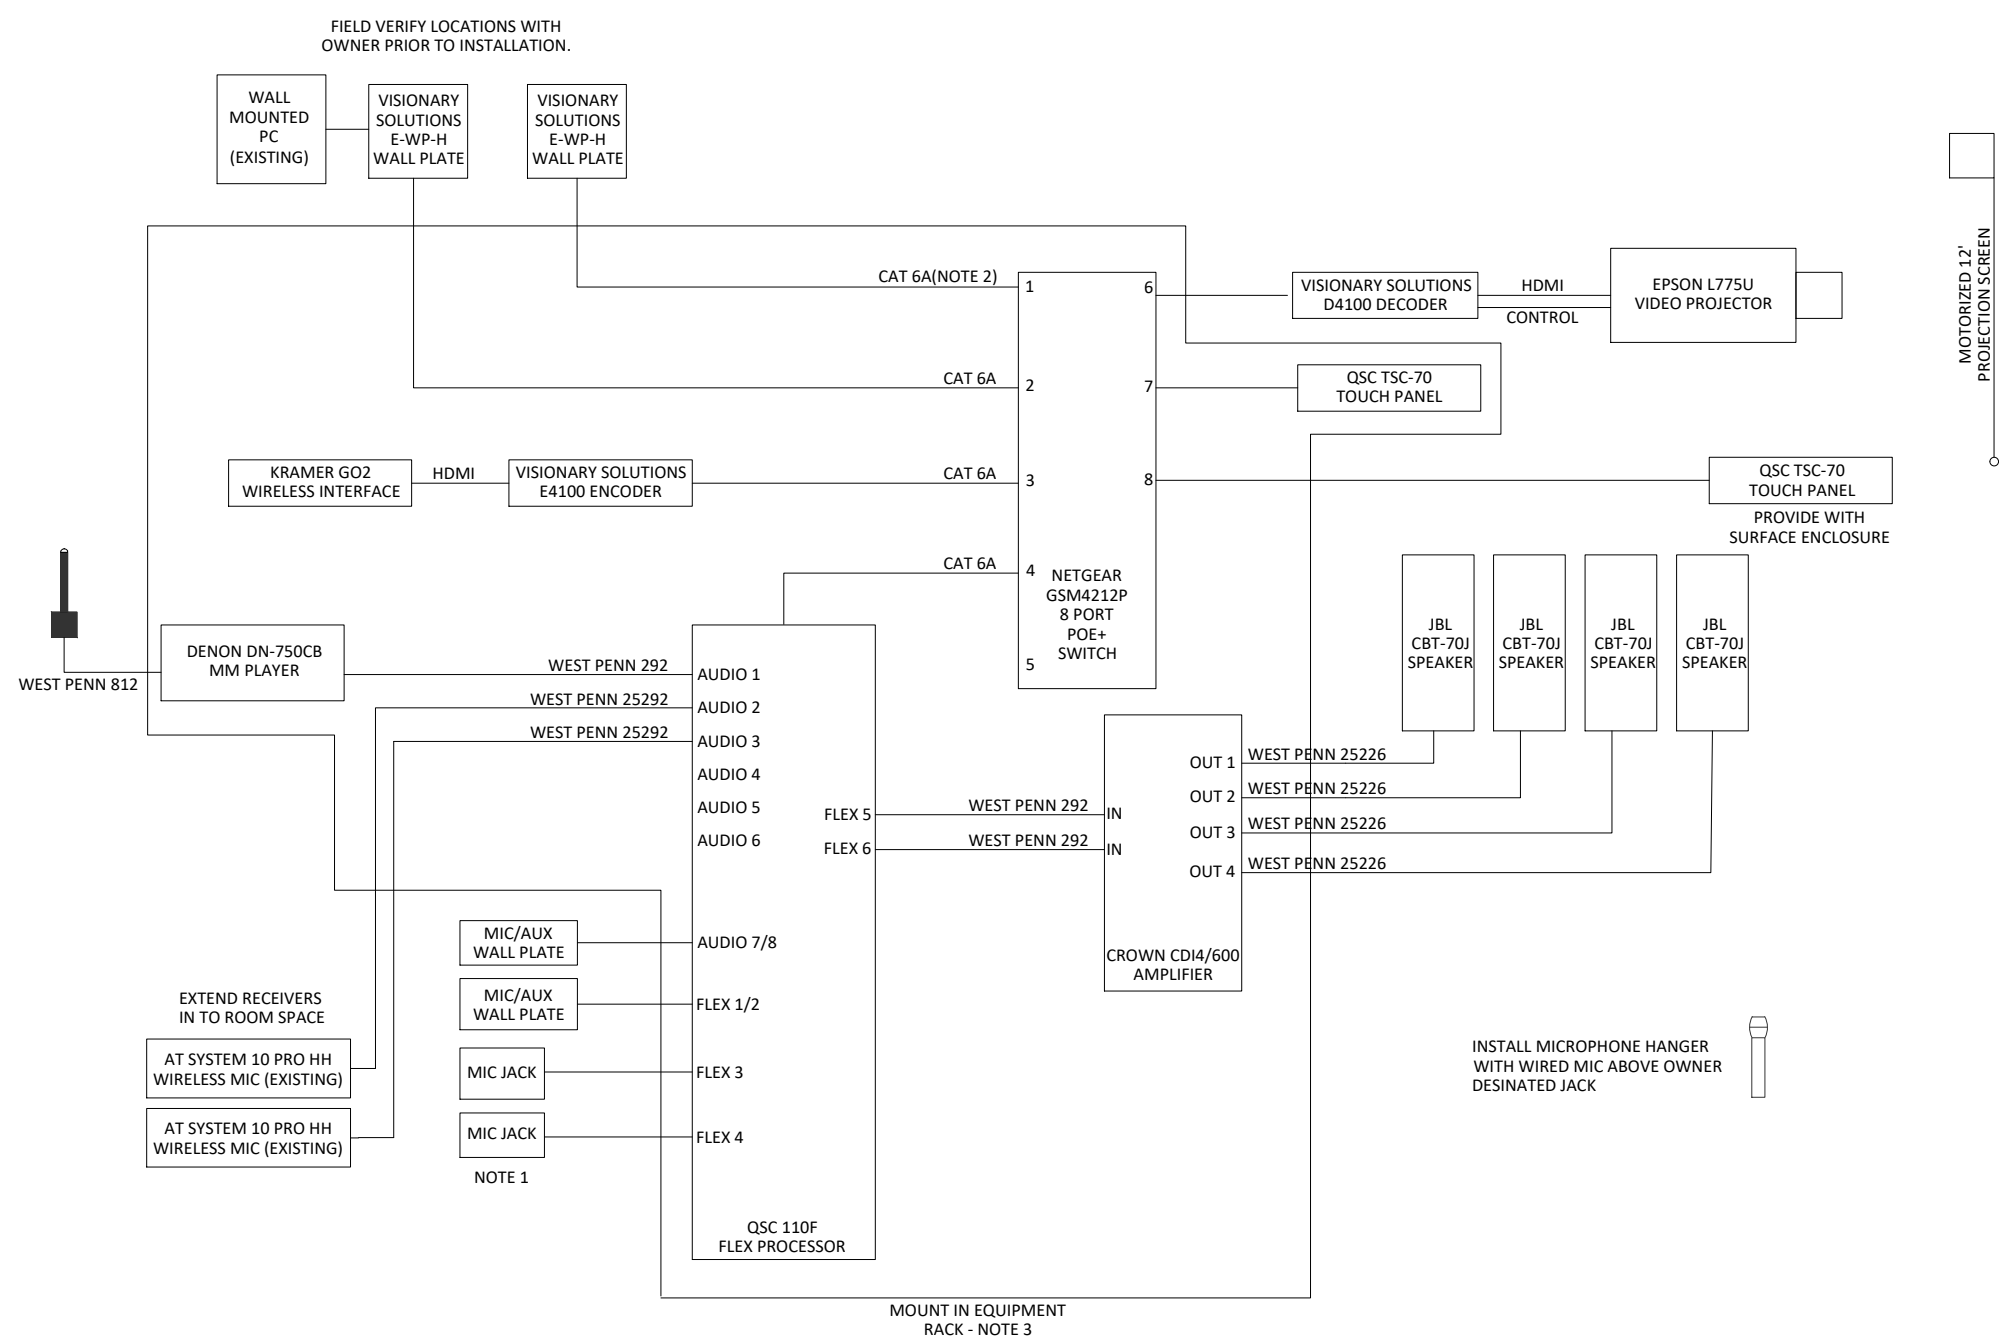

NOTE 1 - NUMBER OF MIC JACKS PER ROOM MAY DIFFER. SEE PLANS. ALL JACKS ARE TO BE REWIRED WITH WEST PENN 25292.
NOTE 2 - ALL CAT6A CABLES SHALL BE SHIELDED AND PLENUM RATED. PROVIDE SHIELDED CONNECTORS FOR ALL CONNECTIONS
NOTE 3 - REMOVE EXISTING RACK. REUSE EXISTING AUDIO TECHNICA SYSTEM 10 PRO WIRELESS MICROPHONES

2 CAFETERIA AUDIO VIDEO SCHEMATIC
NTS

KEY PLAN

OWNER

Northville Public
Schools

PROJECT NAME

Audio and Video Systems

Northville, MI 48167

PROJECT NO.

25-NPS-AVS-01

ISSUES / REVISIONS

03.12.2025 BIDS

DRAWN BY

BMJ

CHECKED BY

BG

APPROVED BY


SJB

SHEET NAME

WINCHESTER
ELEMENTARY
CAFETERIA AVS

SHEET NO.

TA110

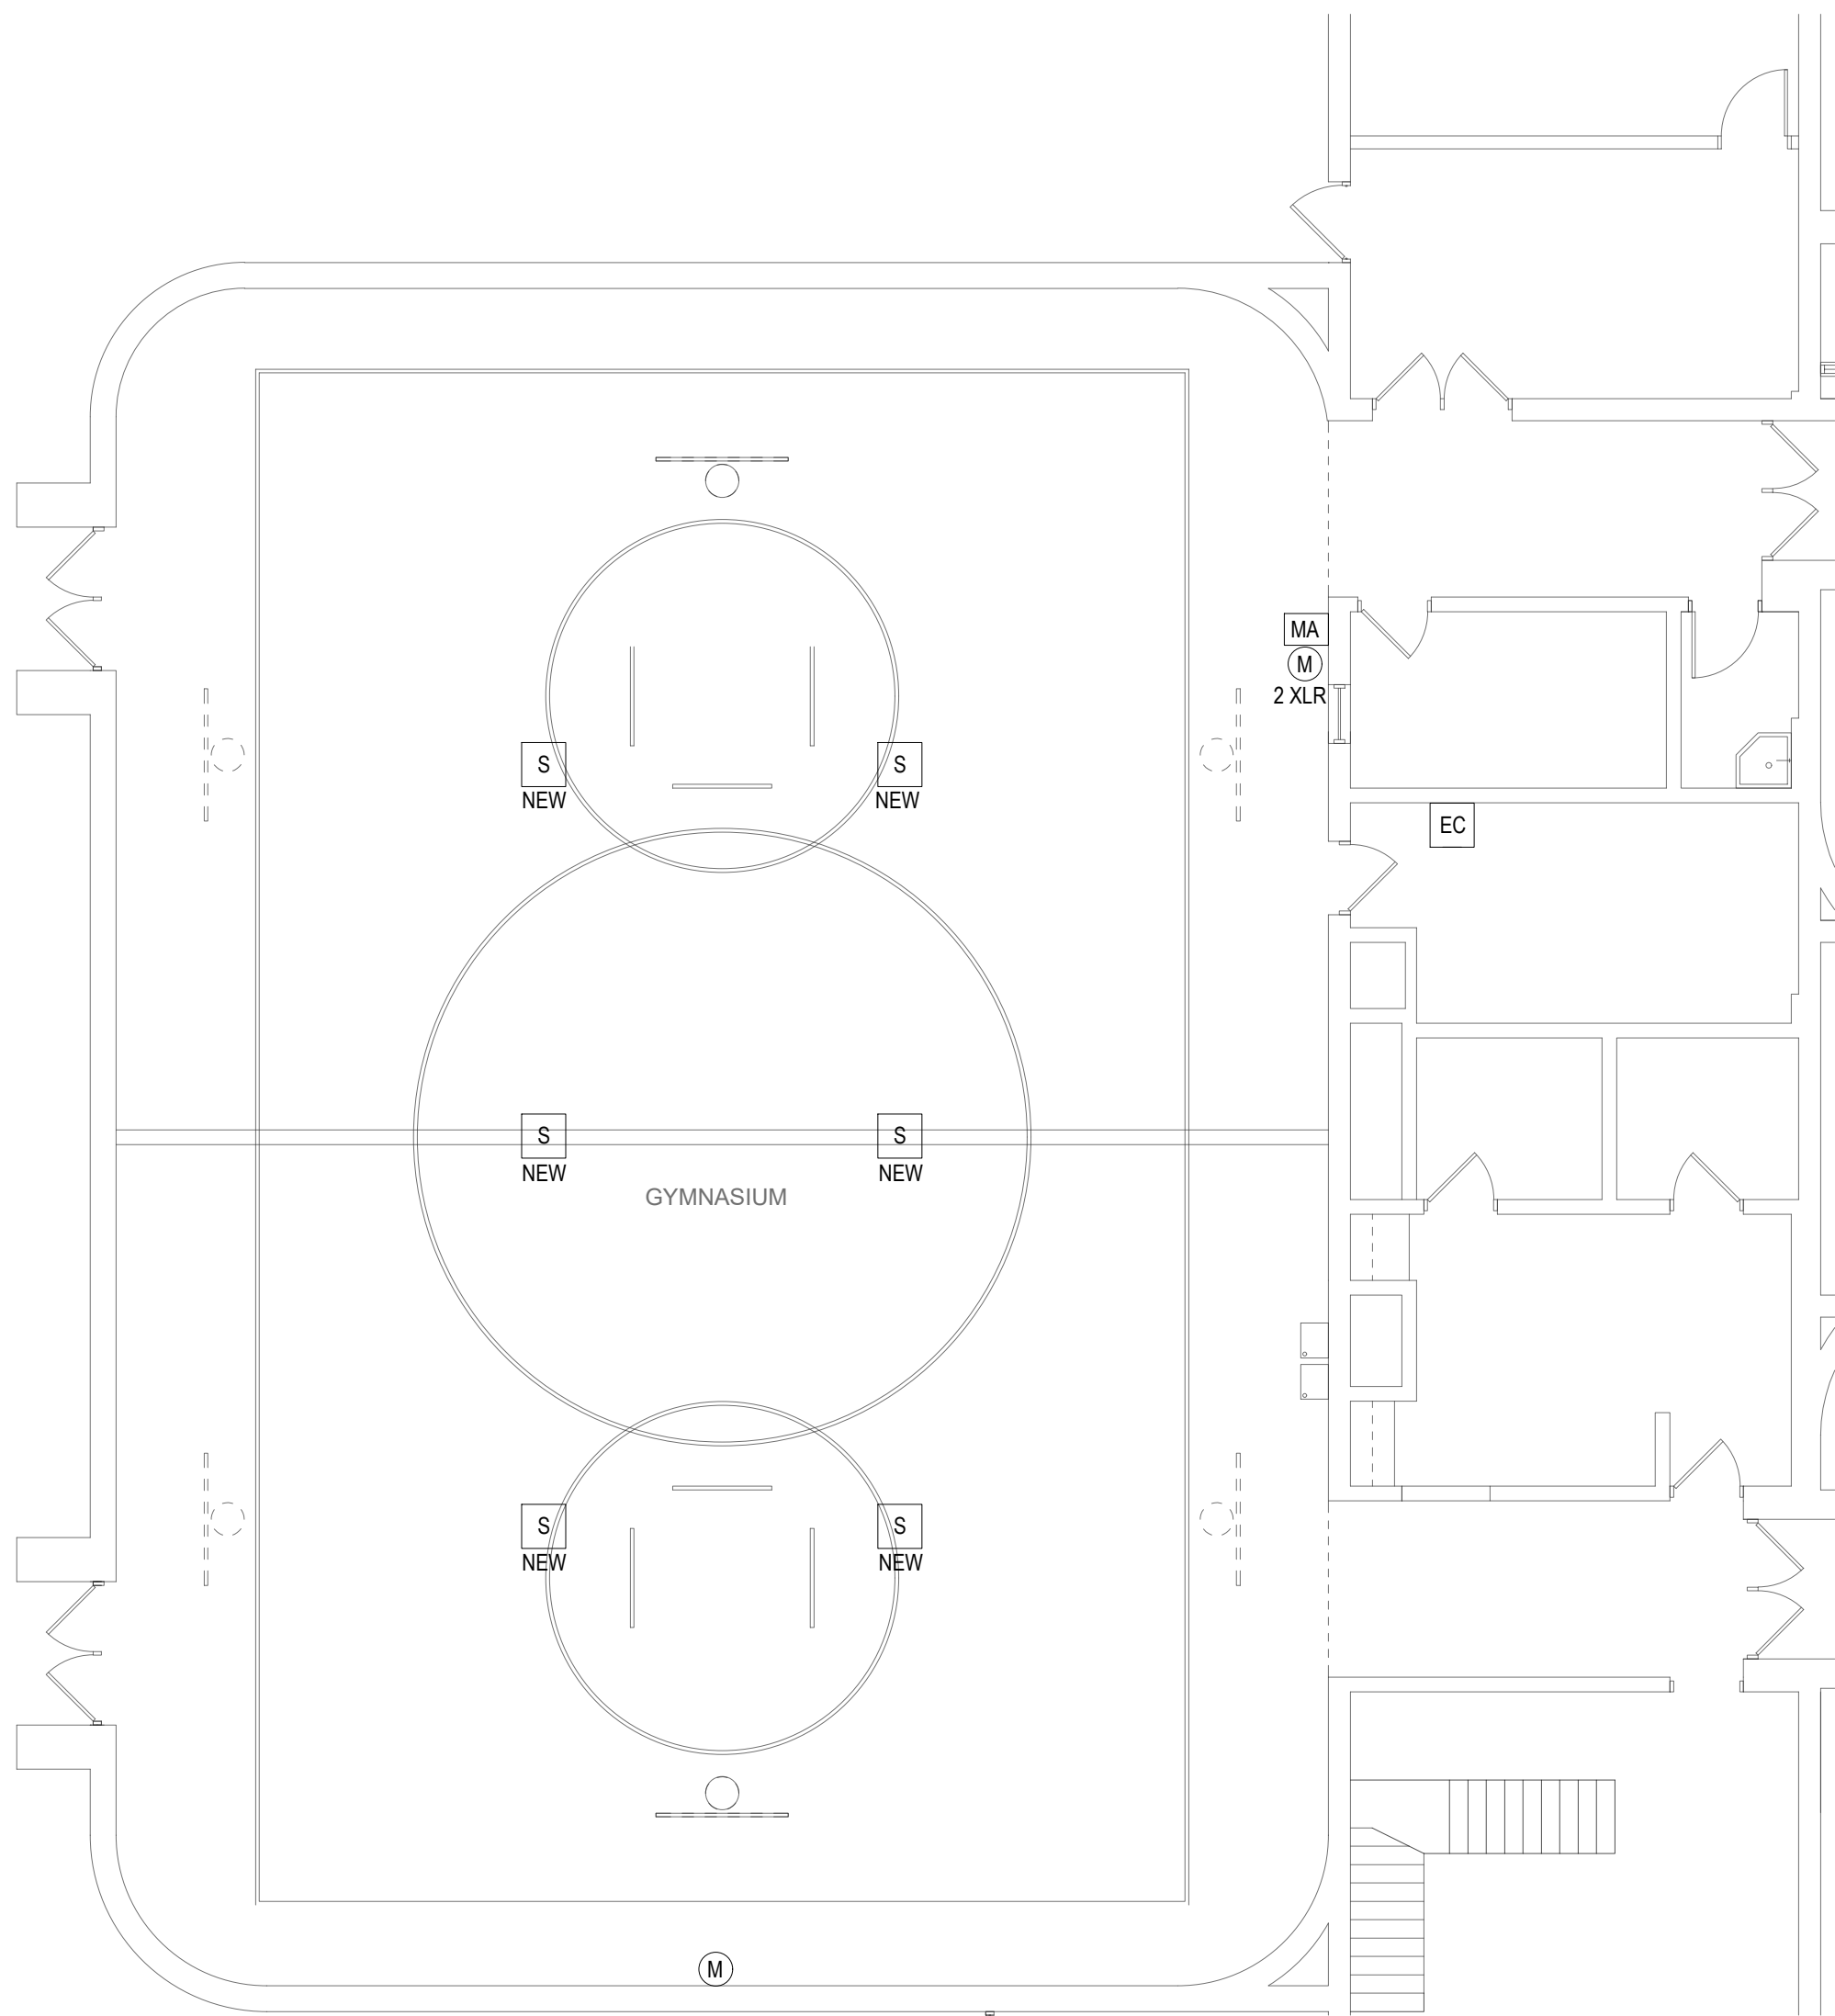


1 GYMNASIUM AUDIO VIDEO SYSTEM
1/8" = 1'-0"

GENERAL AUDIO VIDEO NOTES:

1. FINAL LOCATIONS TO BE FIELD VERIFIED WITH OWNER PRIOR TO INSTALLATION.
2. PROVIDE SAFETY CABLES FOR ALL SPEAKERS.

AUDIO VIDEO FLOOR PLAN SYMBOL LEGEND:

- EC EQUIPMENT CABINET
S SPEAKER
M MICROPHONE
MA MIC/AUX INPUT

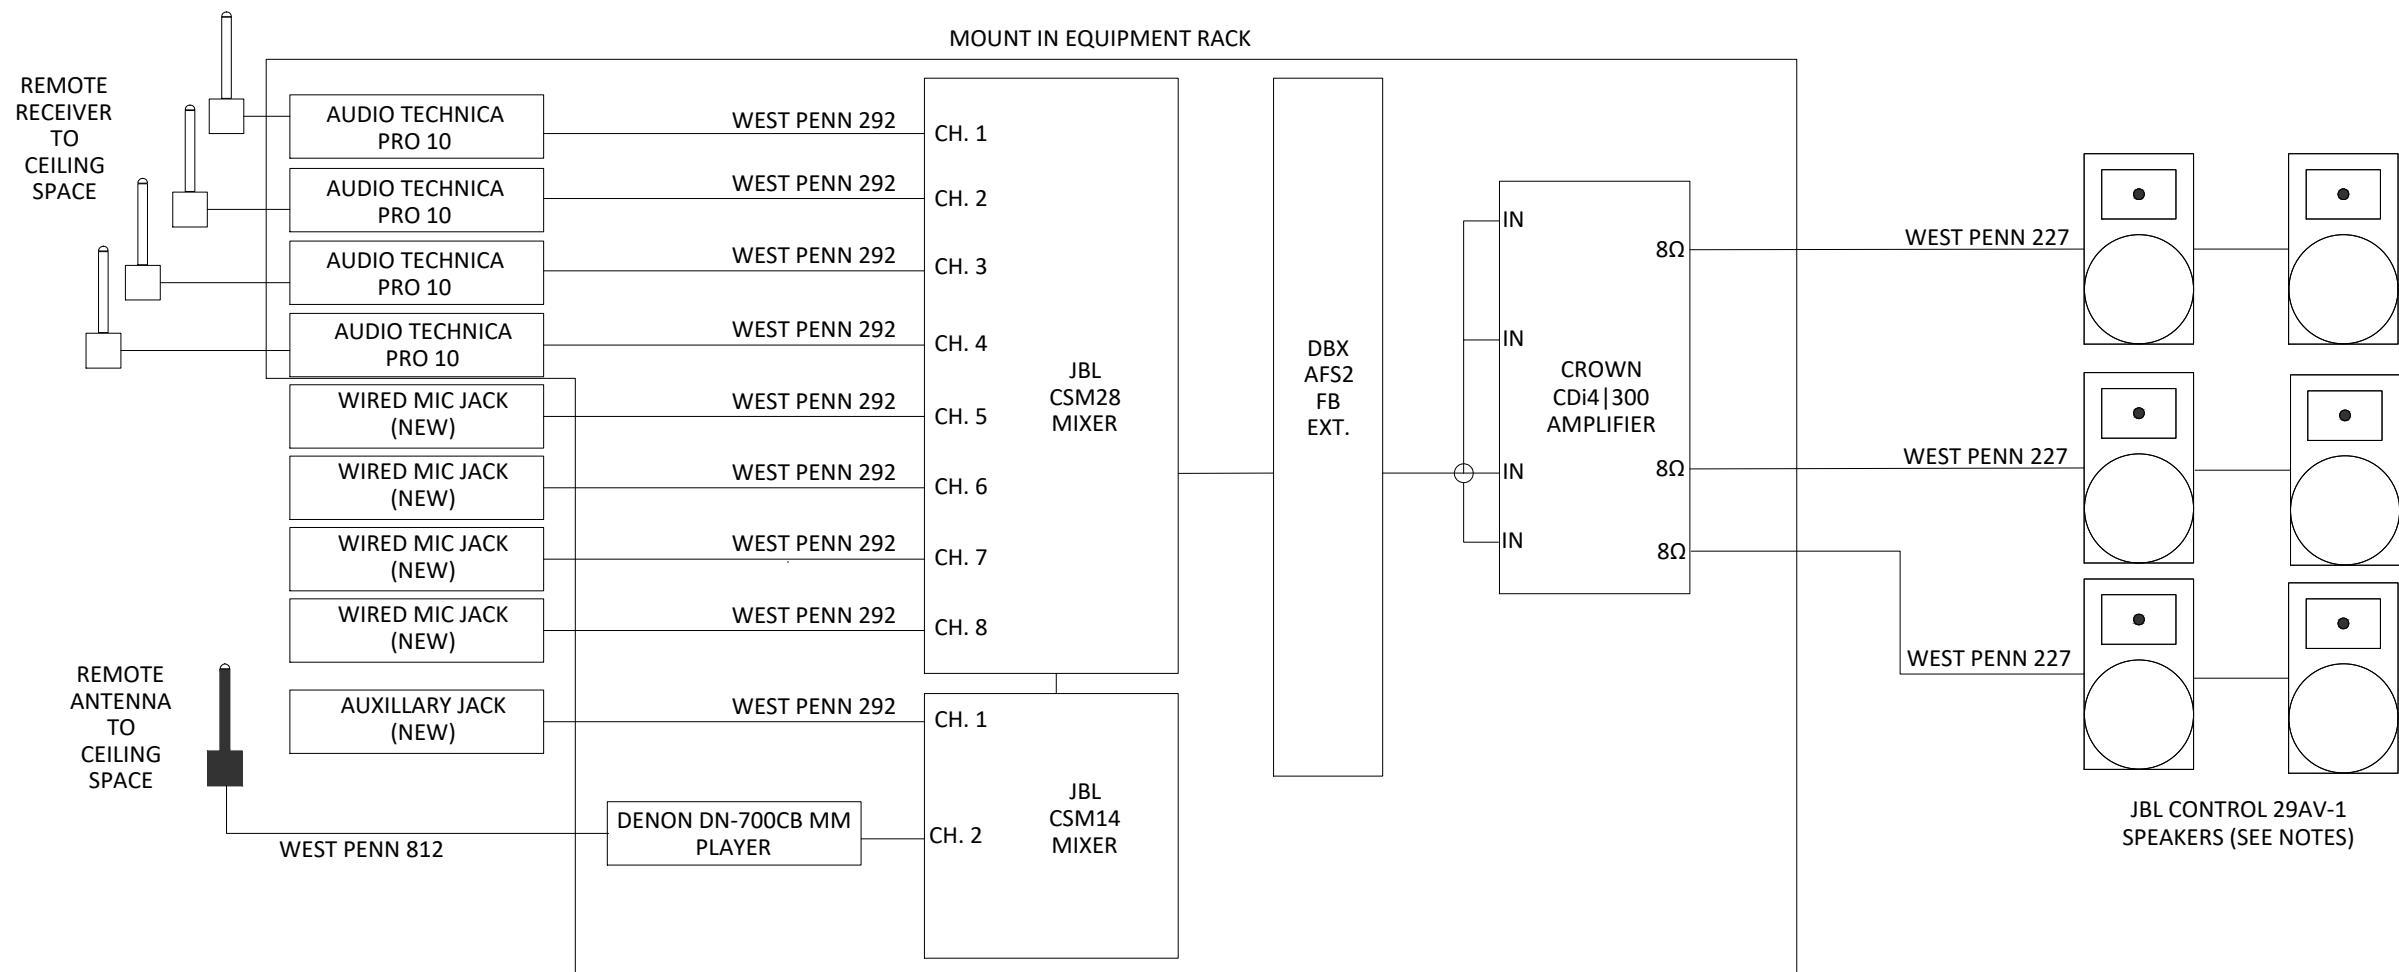

1. AT MORaine ELEMENTARY - REUSE EXISTING SIX SPEAKERS.
2. AT RIDGEWOOD, WINCHESTER AND SILVER SPRINGS ELEMENTARY - ADD TWO (2) SPEAKERS TO EXISTING. VERIFY EXISTING SPEAKER TYPE PRIOR TO ORDERING. ASSUME JBL CONTROL 29AV-1 FOR BID PURPOSES.
3. AT THORNTON CREEK - REMOVE EXISTING ANTIQUE SPEAKERS.
4. AT COOKE SCHOOL - REUSE EXISTING SIX SPEAKERS.

1 GYMNASIUM AUDIO VIDEO SCHEMATIC
1/8" = 1'-0"

KEY PLAN

OWNER

Northville Public
Schools

PROJECT NAME

Audio and Video Systems

Northville, MI 48167

PROJECT NO.

25-NPS-AVS-01

ISSUES / REVISIONS

03.12.2025 BIDS

DRAWN BY

BMJ

CHECKED BY

BG

APPROVED BY


SJB

SHEET NAME

WINCHESTER
ELEMENTARY GYM
AVS

SHEET NO.

TA111

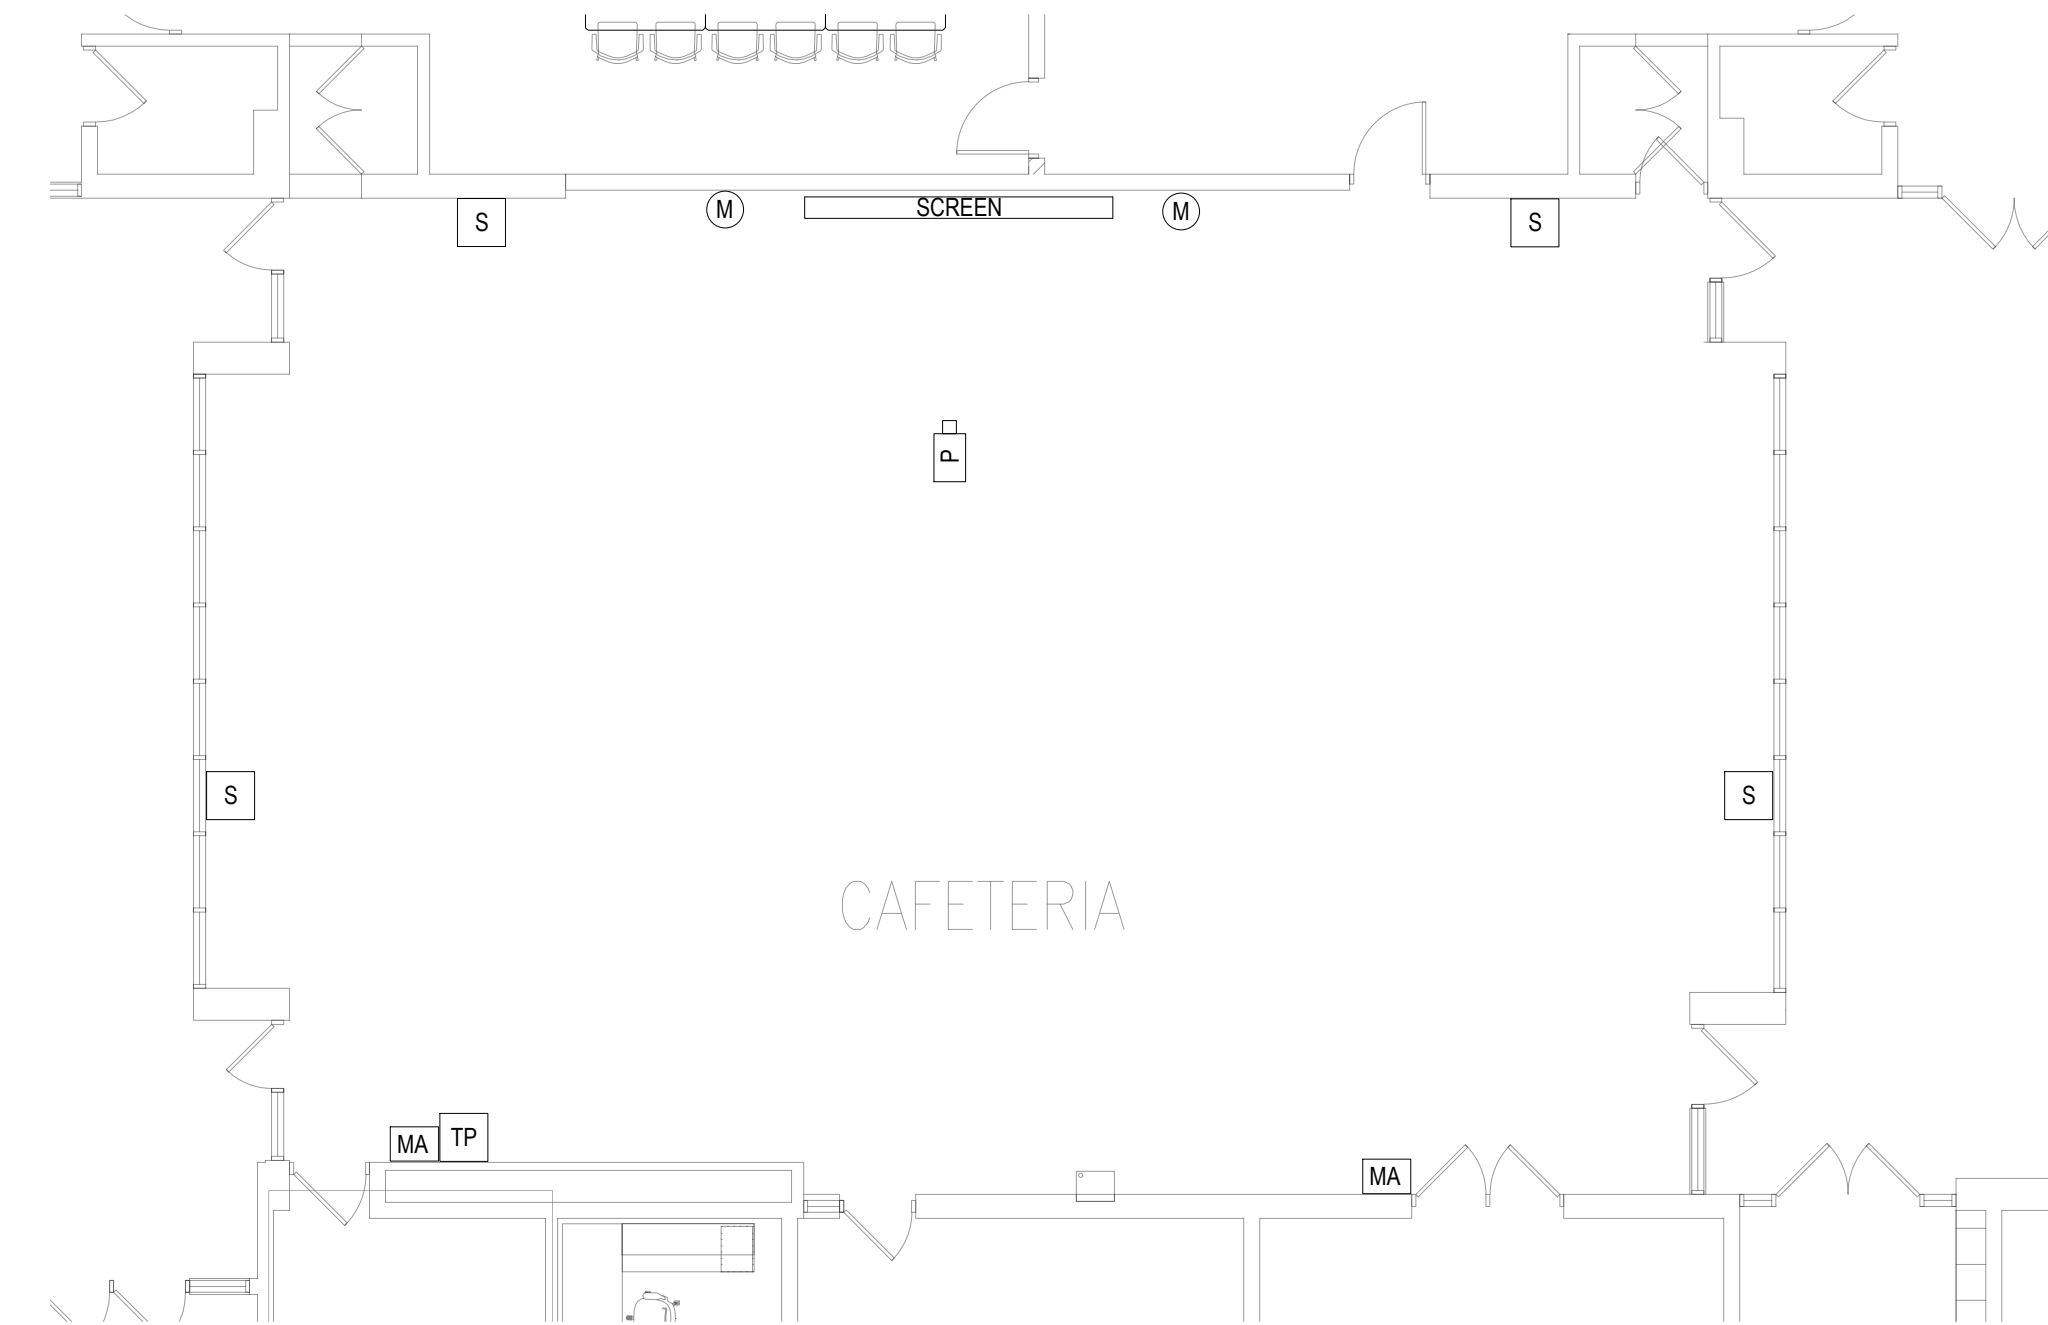


GENERAL AUDIO VIDEO NOTES:

1. FINAL LOCATIONS TO BE FIELD VERIFIED WITH OWNER PRIOR TO INSTALLATION.
2. PROVIDE SAFETY CABLES FOR ALL SPEAKERS.

AUDIO VIDEO FLOOR PLAN SYMBOL LEGEND:

- EC EQUIPMENT CABINET
- S SPEAKER
- TP TOUCH PANEL
- M MICROPHONE
- MA MIC/AUX INPUT
- V HDMI VIDEO INPUT PLATE
- P CEILING MOUNTED PROJECTOR
- SCREEN PROJECTION SCREEN

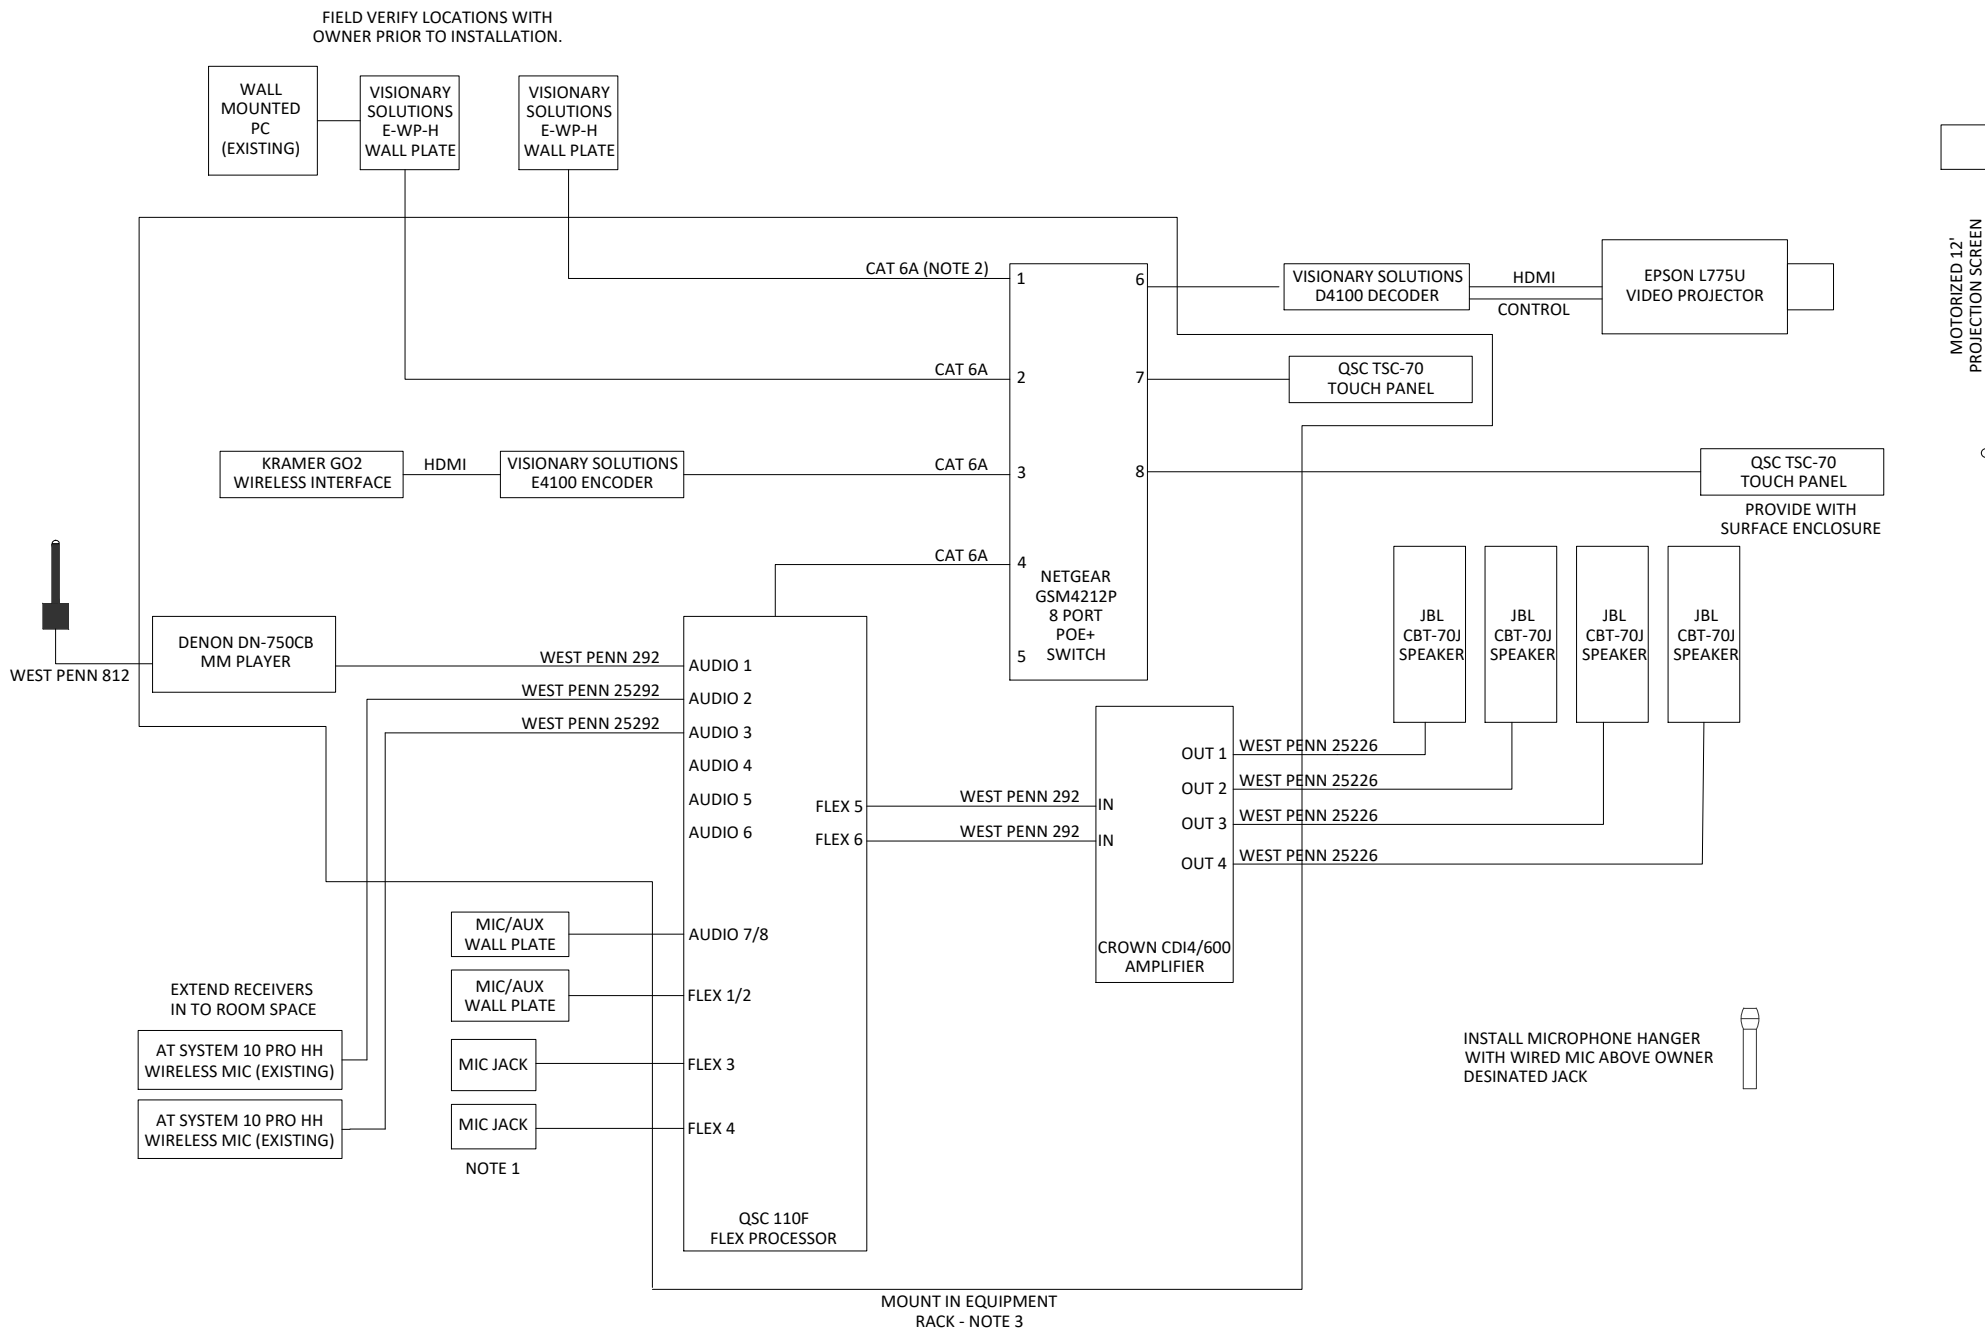

NOTE 1 - NUMBER OF MIC JACKS PER ROOM MAY DIFFER, SEE PLANS. ALL JACKS ARE TO BE REWIRED WITH WEST PENN 25292.
NOTE 2 - ALL CAT6A CABLES SHALL BE SHIELDED AND PREMIUM RATED. PROVIDE SHIELDED CONNECTORS FOR ALL CONNECTIONS
NOTE 3 - REMOVE EXISTING RACK. REUSE EXISTING AUDIO TECHNICA SYSTEM 10 PRO WIRELESS MICROPHONES

KEY PLAN

OWNER

Northville Public
Schools

PROJECT NAME

Audio and Video Systems

Northville, MI 48167

PROJECT NO.

25-NPS-AVS-01

ISSUES / REVISIONS

03.12.2025 BIDS

DRAWN BY

BMJ

CHECKED BY

BG

APPROVED BY


SJB

SHEET NAME

COOKE SCHOOL
CAFETERIA AVS

SHEET NO.

TA112

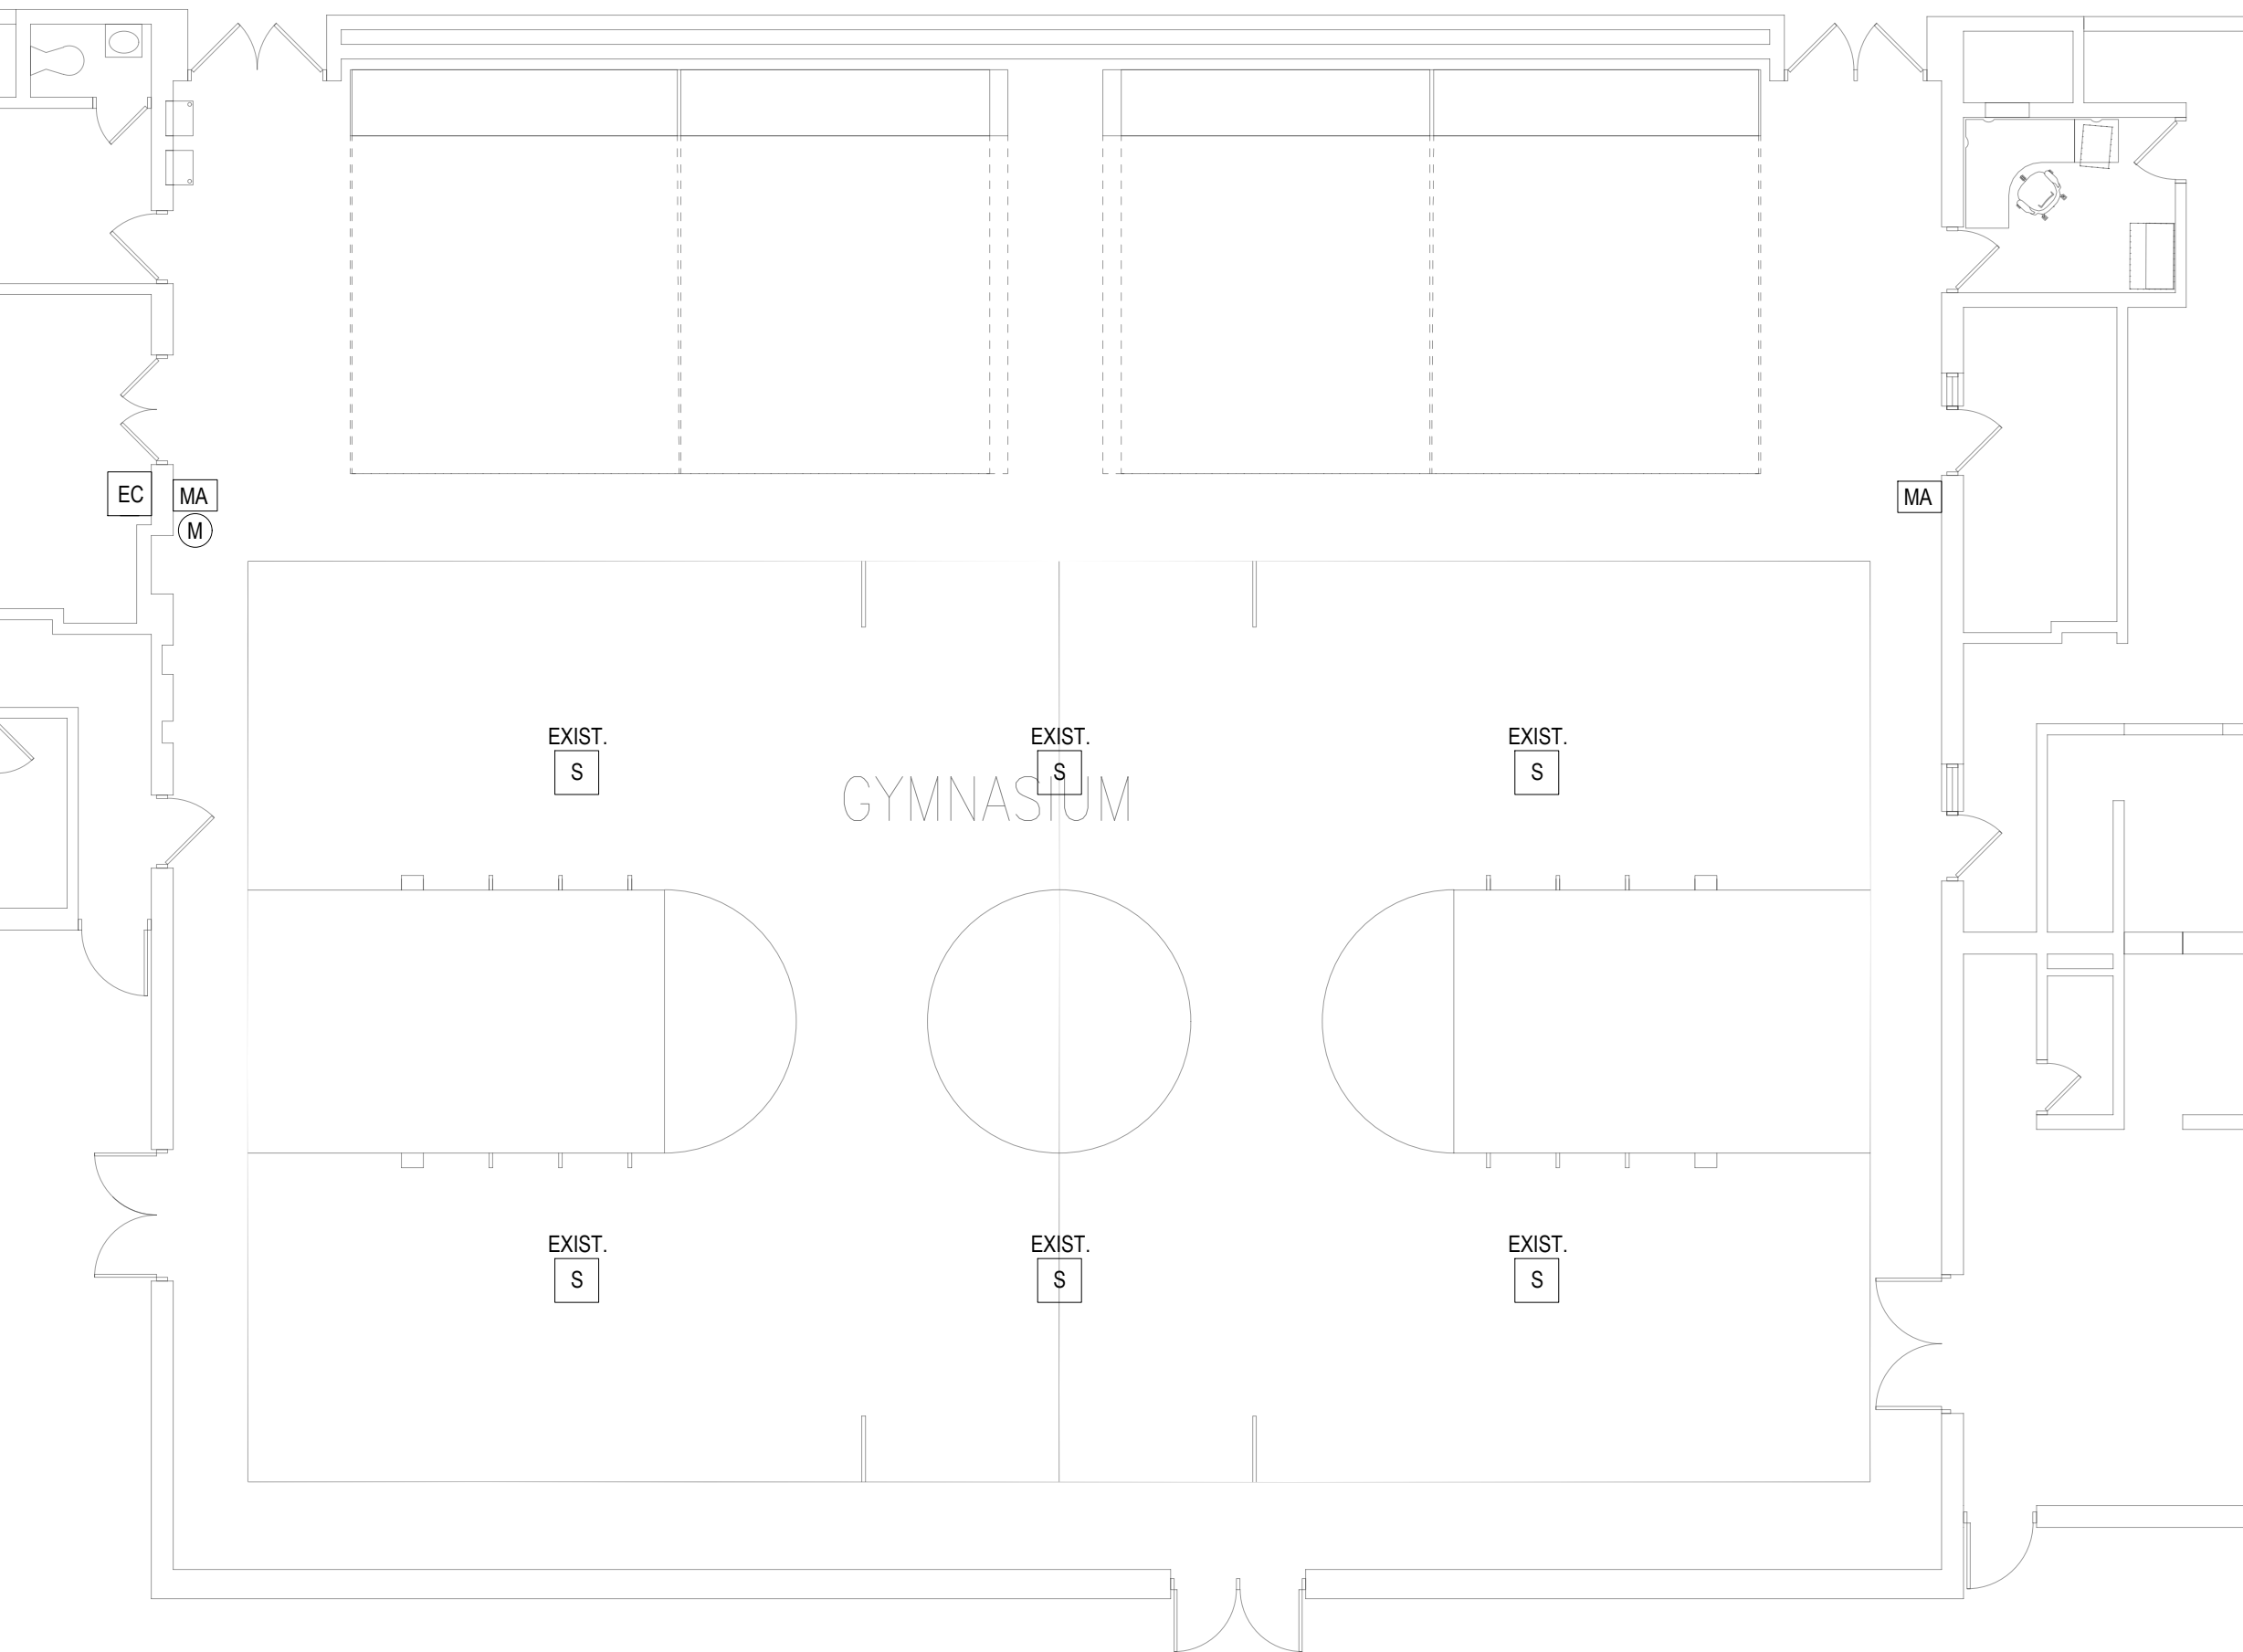


GENERAL AUDIO VIDEO NOTES:

1. FINAL LOCATIONS TO BE FIELD VERIFIED WITH OWNER PRIOR TO INSTALLATION.
2. PROVIDE SAFETY CABLES FOR ALL SPEAKERS.

AUDIO VIDEO FLOOR PLAN SYMBOL LEGEND:

- EC EQUIPMENT CABINET
- S SPEAKER
- M MICROPHONE
- MA MIC/AUX INPUT

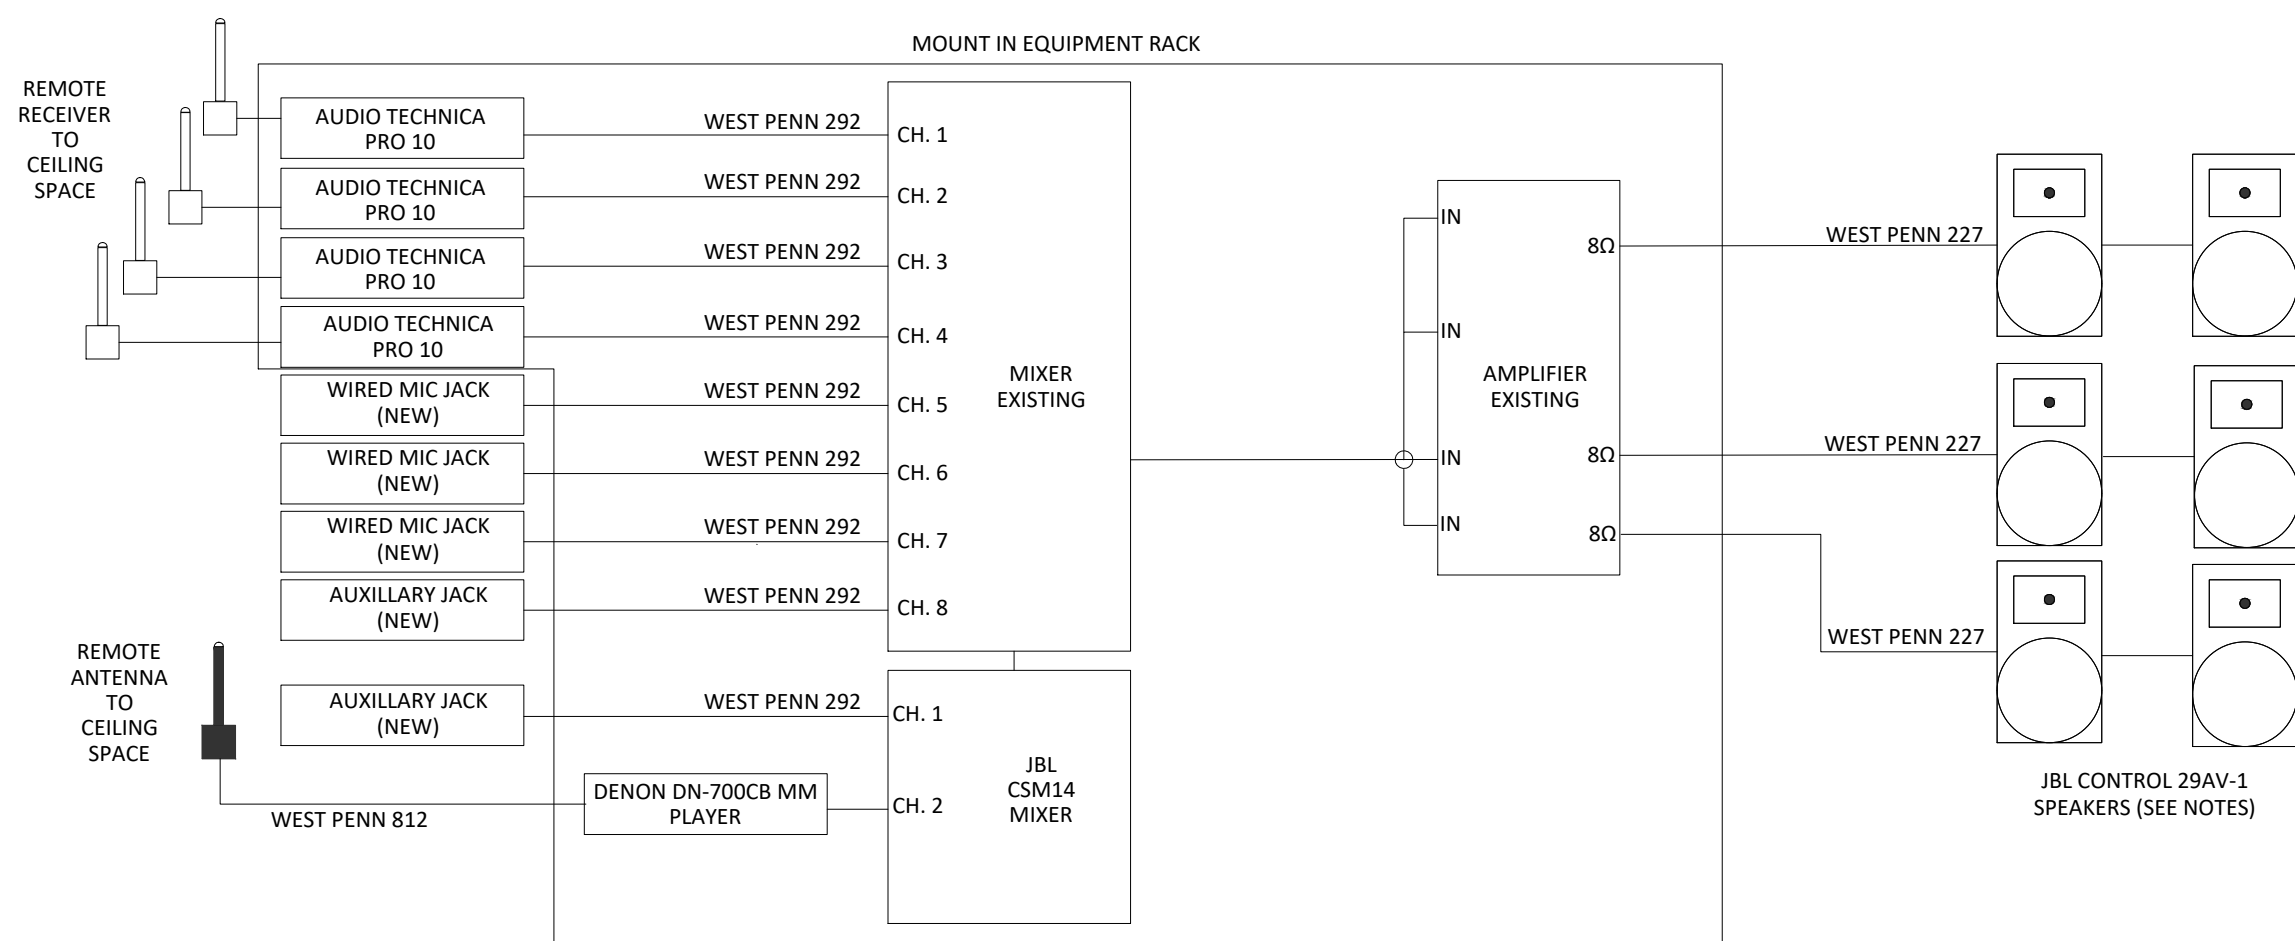

1. AT MORAINÉ ELEMENTARY - REUSE EXISTING SIX SPEAKERS.
2. AT RIDGEWOOD, WINCHESTER AND SILVER SPRINGS ELEMENTARY - ADD TWO (2) SPEAKERS TO EXISTING. VERIFY EXISTING SPEAKER TYPE PRIOR TO ORDERING. ASSUME JBL CONTROL 29AV-1 FOR BID PURPOSES.
3. AT THORNTON CREEK - REMOVE EXISTING ANTIQUE SPEAKERS.
4. AT COOKE SCHOOL - REUSE EXISTING SIX SPEAKERS.

KEY PLAN

OWNER

Northville Public
Schools

PROJECT NAME

Audio and Video Systems

Northville, MI 48167

PROJECT NO.

25-NPS-AVS-01

ISSUES / REVISIONS

03.12.2025 BIDS

DRAWN BY

BMJ

CHECKED BY

BG

APPROVED BY


SJB

SHEET NAME

COOKE SCHOOL
GYM AVS

SHEET NO.

TA113

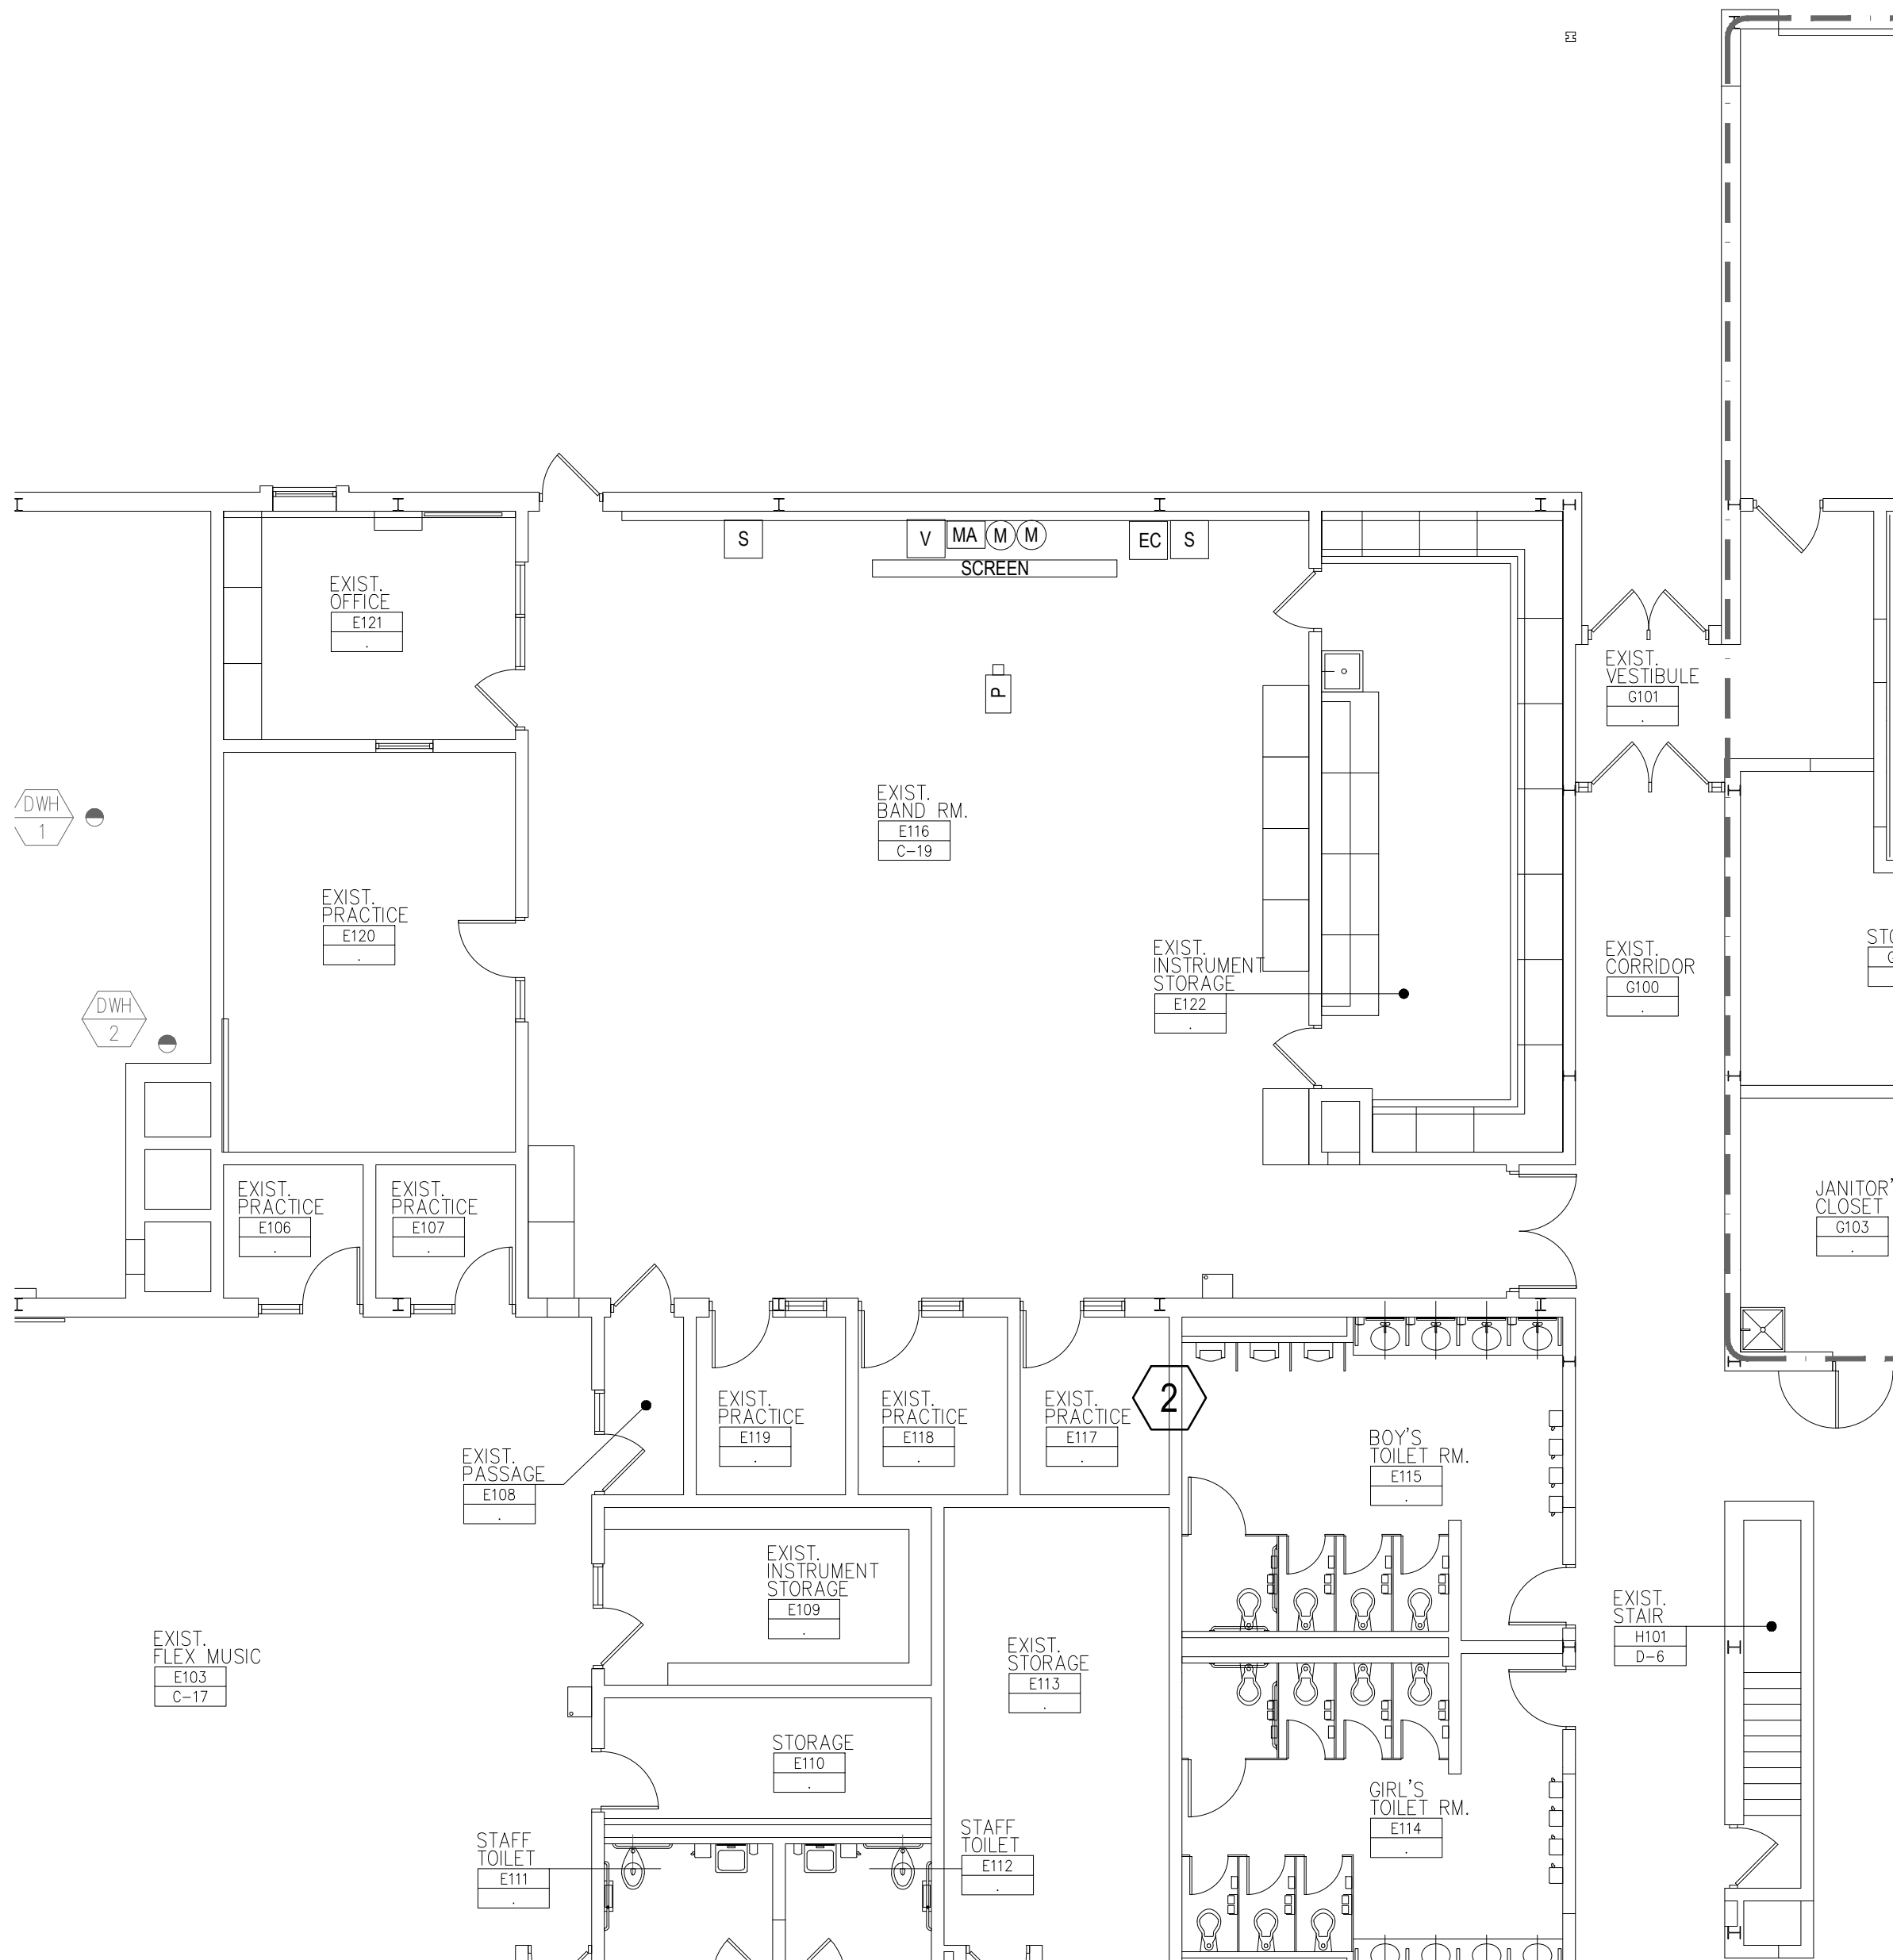


1 BAND ROOM AUDIO VIDEO SYSTEM
1/8" = 1'-0"

GENERAL AUDIO VIDEO NOTES:

1. FINAL LOCATIONS TO BE FIELD VERIFIED WITH OWNER PRIOR TO INSTALLATION.
2. PROVIDE SAFETY CABLES FOR ALL SPEAKERS.

AUDIO VIDEO FLOOR PLAN SYMBOL LEGEND:

- EC EQUIPMENT CABINET
- S SPEAKER
- M MICROPHONE
- MA MIC/AUX INPUT

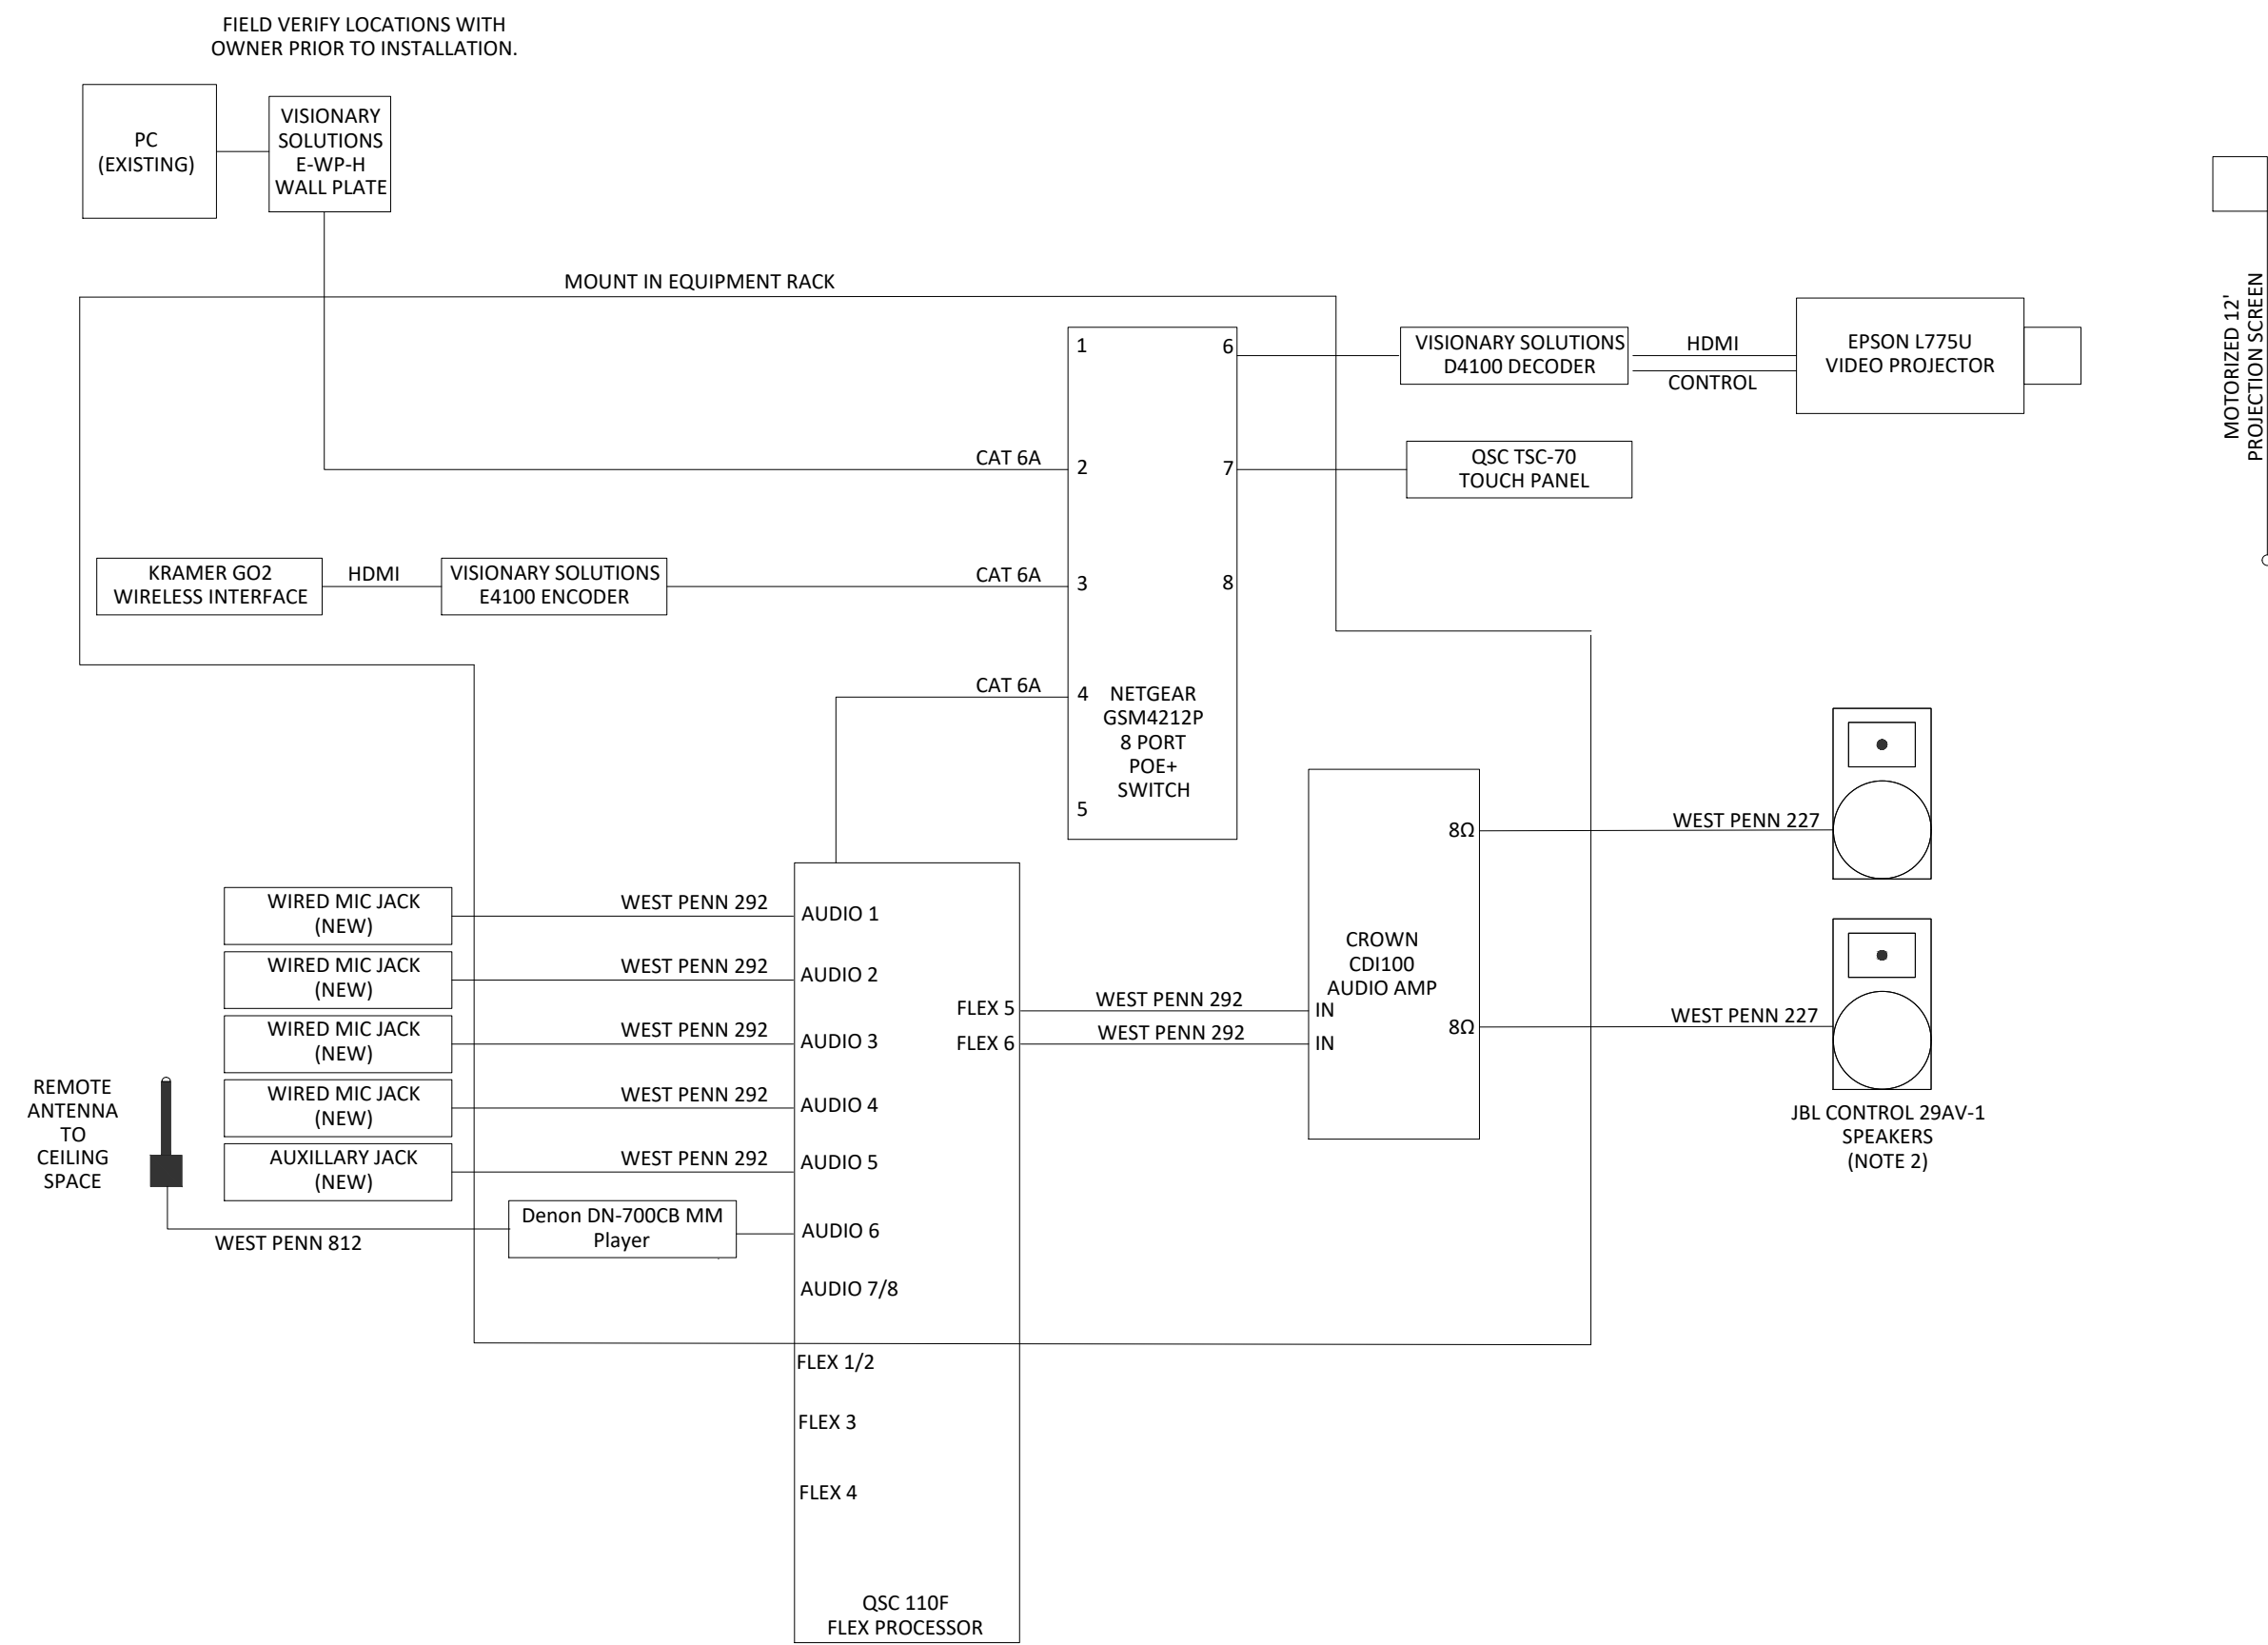

1 BAND ROOM AUDIO VIDEO SCHEMATIC
1/8" = 1'-0"

KEY PLAN

OWNER

Northville Public
Schools

PROJECT NAME

Audio and Video Systems

Northville, MI 48167

PROJECT NO.

25-NPS-AVS-01

ISSUES / REVISIONS

03.12.2025 BIDS

DRAWN BY

BMJ

CHECKED BY

BG

APPROVED BY

SJB

SHEET NAME

MEADS MILL
MIDDLE SCHOOL
BAND ROOM AVS

SHEET NO.


TA114

GENERAL AUDIO VIDEO NOTES:


1. FINAL LOCATIONS TO BE FIELD VERIFIED WITH OWNER PRIOR TO INSTALLATION.
2. PROVIDE SAFETY CABLES FOR ALL SPEAKERS.

AUDIO VIDEO FLOOR PLAN SYMBOL LEGEND:

EC	EQUIPMENT CABINET
S	SPEAKER
TP	TOUCH PANEL
M	MICROPHONE
MA	MIC/AUX INPUT
V	HDMI VIDEO INPUT PLATE
P	CEILING MOUNTED PROJECTOR
SCREEN	PROJECTION SCREEN

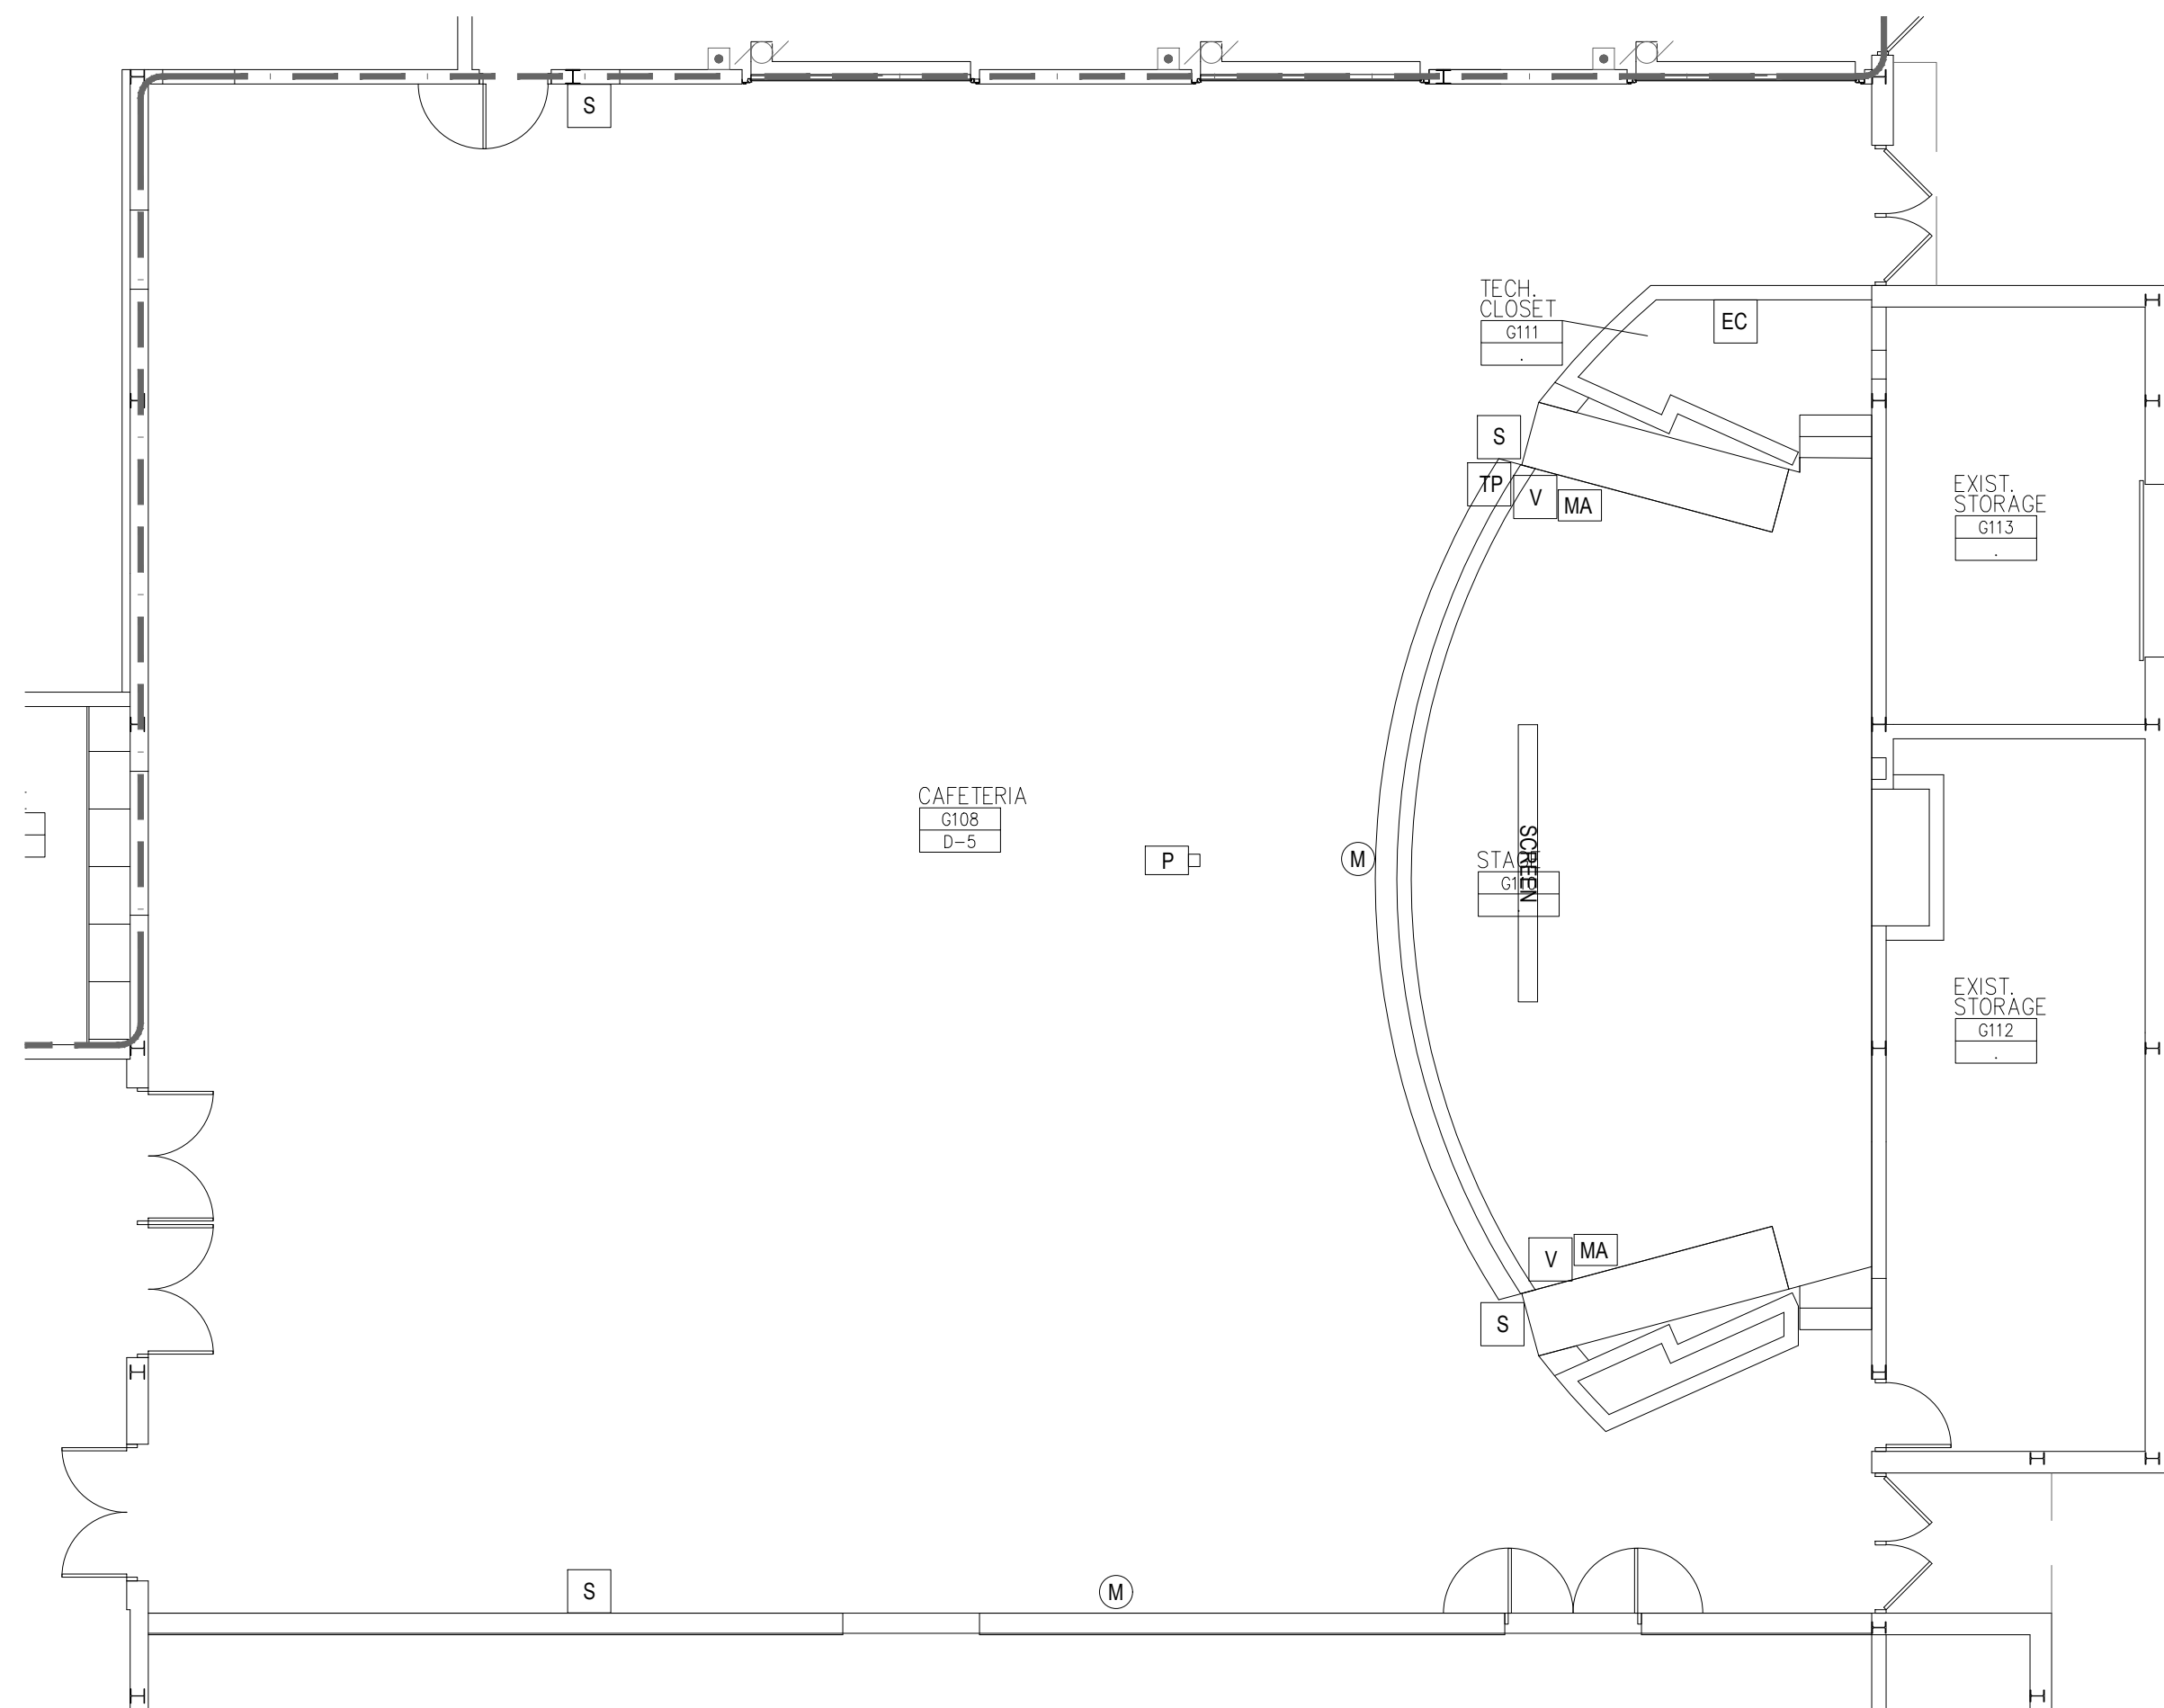

1 CAFETERIA AUDIO VIDEO SYSTEM
1/8" = 1'-0"

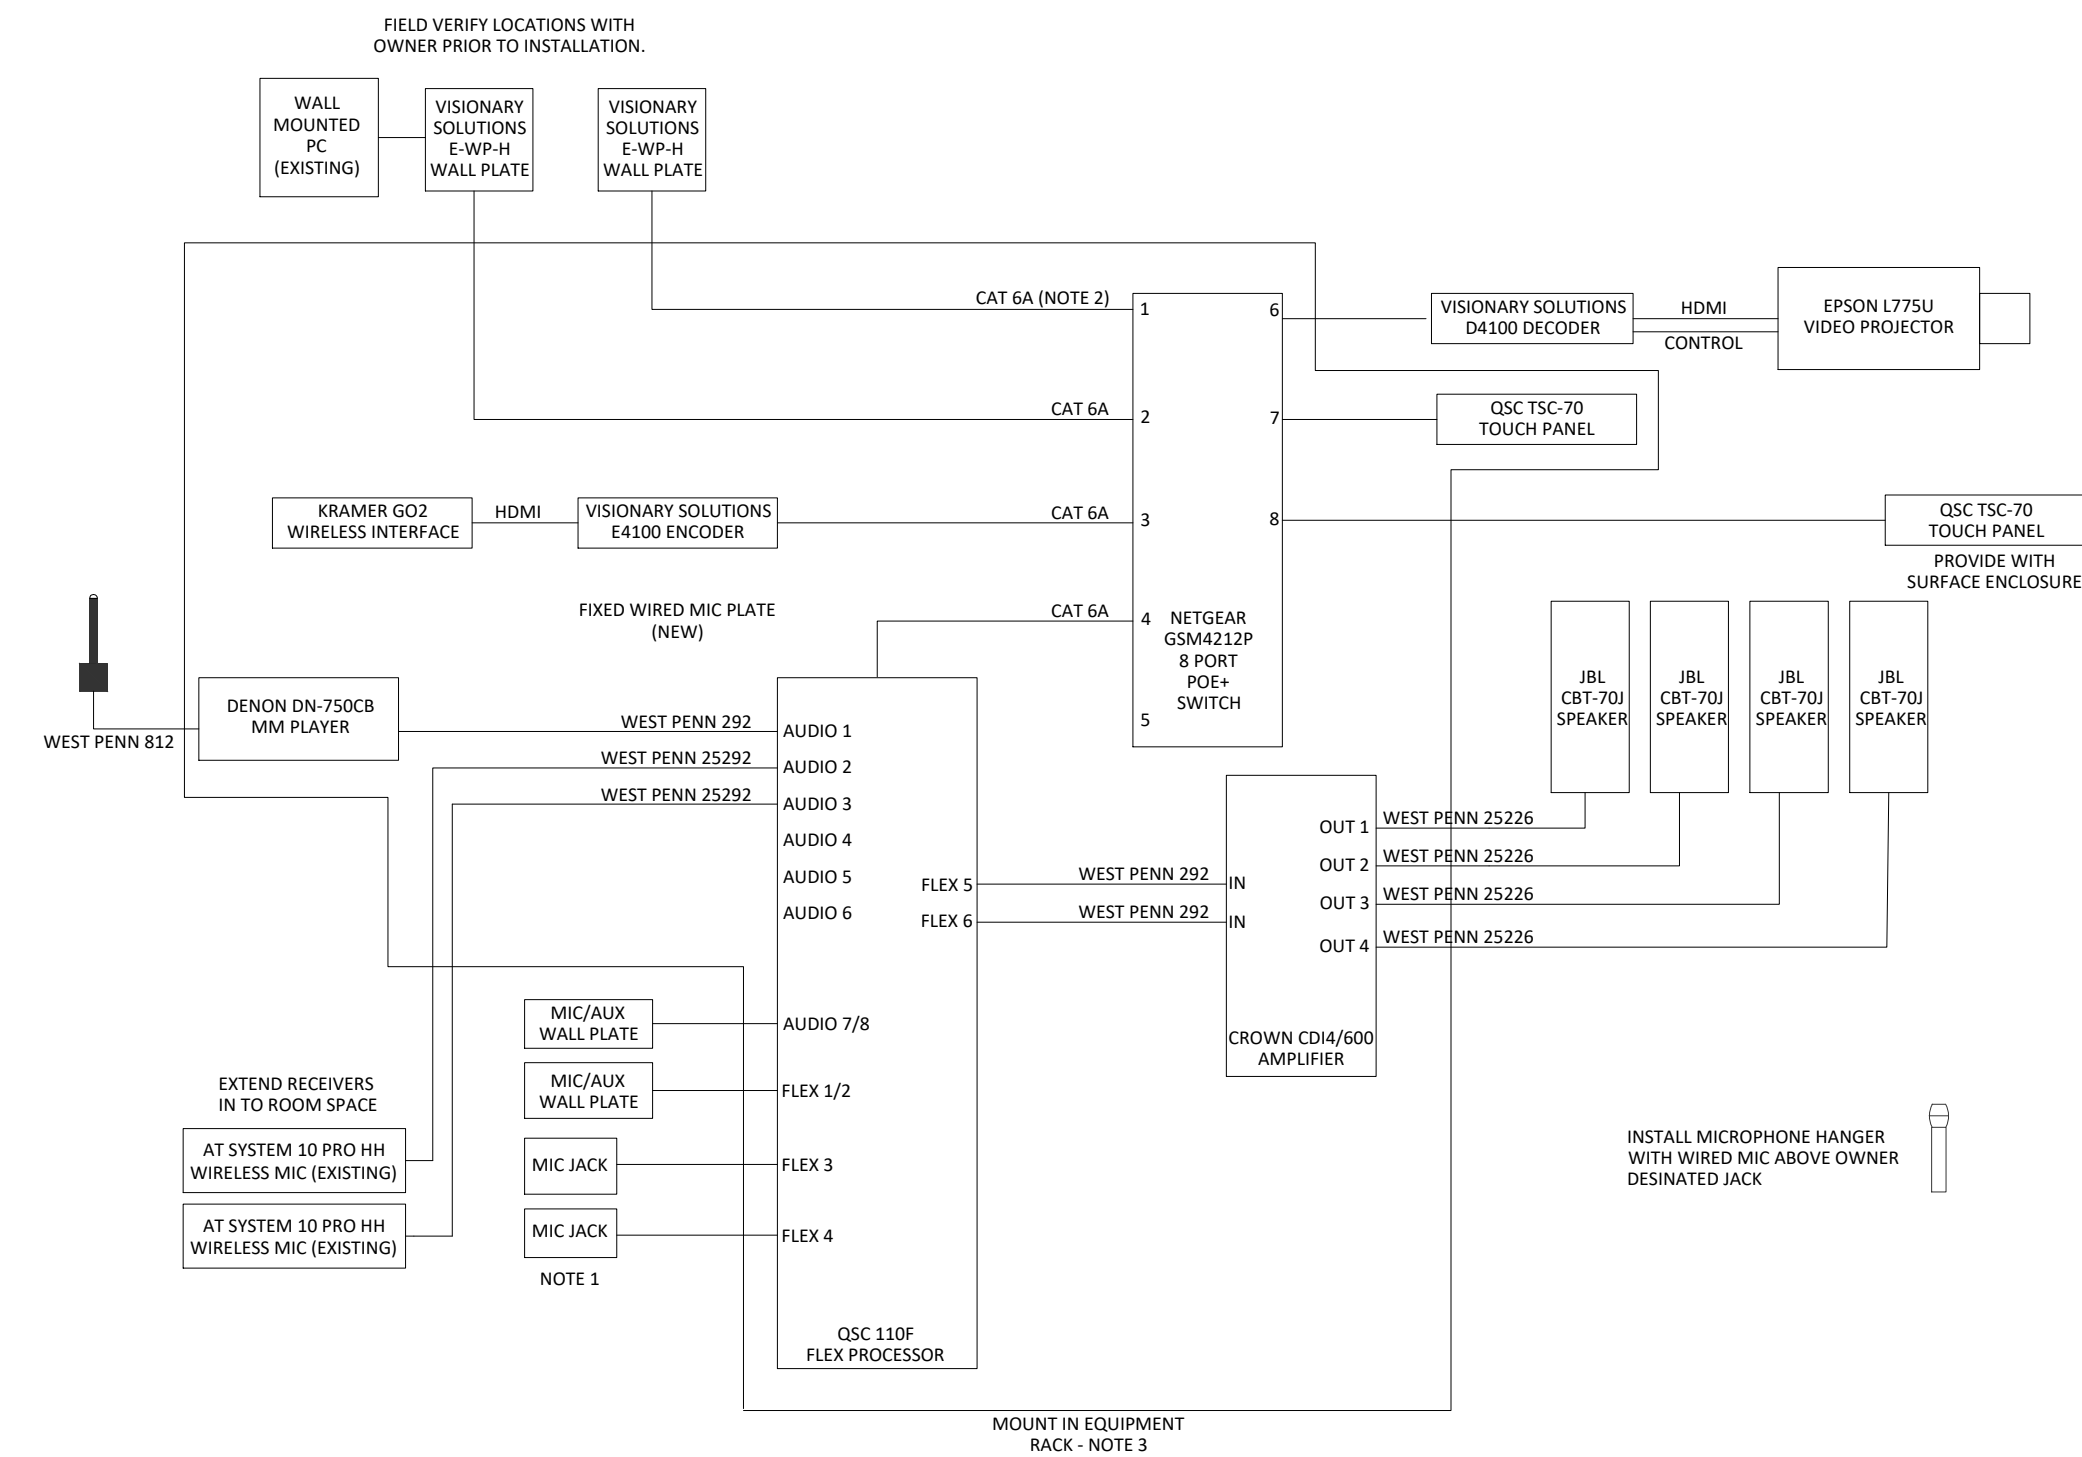

NOTE 1 - NUMBER OF MIC JACKS PER ROOM MAY DIFFER, SEE PLANS. ALL JACKS ARE TO BE REWIRED WITH WEST PENN 25292.
NOTE 2 - ALL CAT6 CABLES SHALL BE SHIELDED AND PLENUM RATED. PROVIDE SHIELDED CONNECTORS FOR ALL CONNECTIONS
NOTE 3 - REMOVE EXISTING RACK. REUSE EXISTING AUDIO TECHNICA SYSTEM 10 PRO WIRELESS MICROPHONES

KEY PLAN

OWNER

Northville Public
Schools

PROJECT NAME

Audio and Video Systems

Northville, MI 48167

PROJECT NO.

25-NPS-AVS-01

ISSUES / REVISIONS

03.12.2025 BIDS

DRAWN BY

BMJ

CHECKED BY

BG

APPROVED BY


SJB

SHEET NAME

MEADS MILL
MIDDLE SCHOOL
CAFETERIA AVS

SHEET NO.

TA115

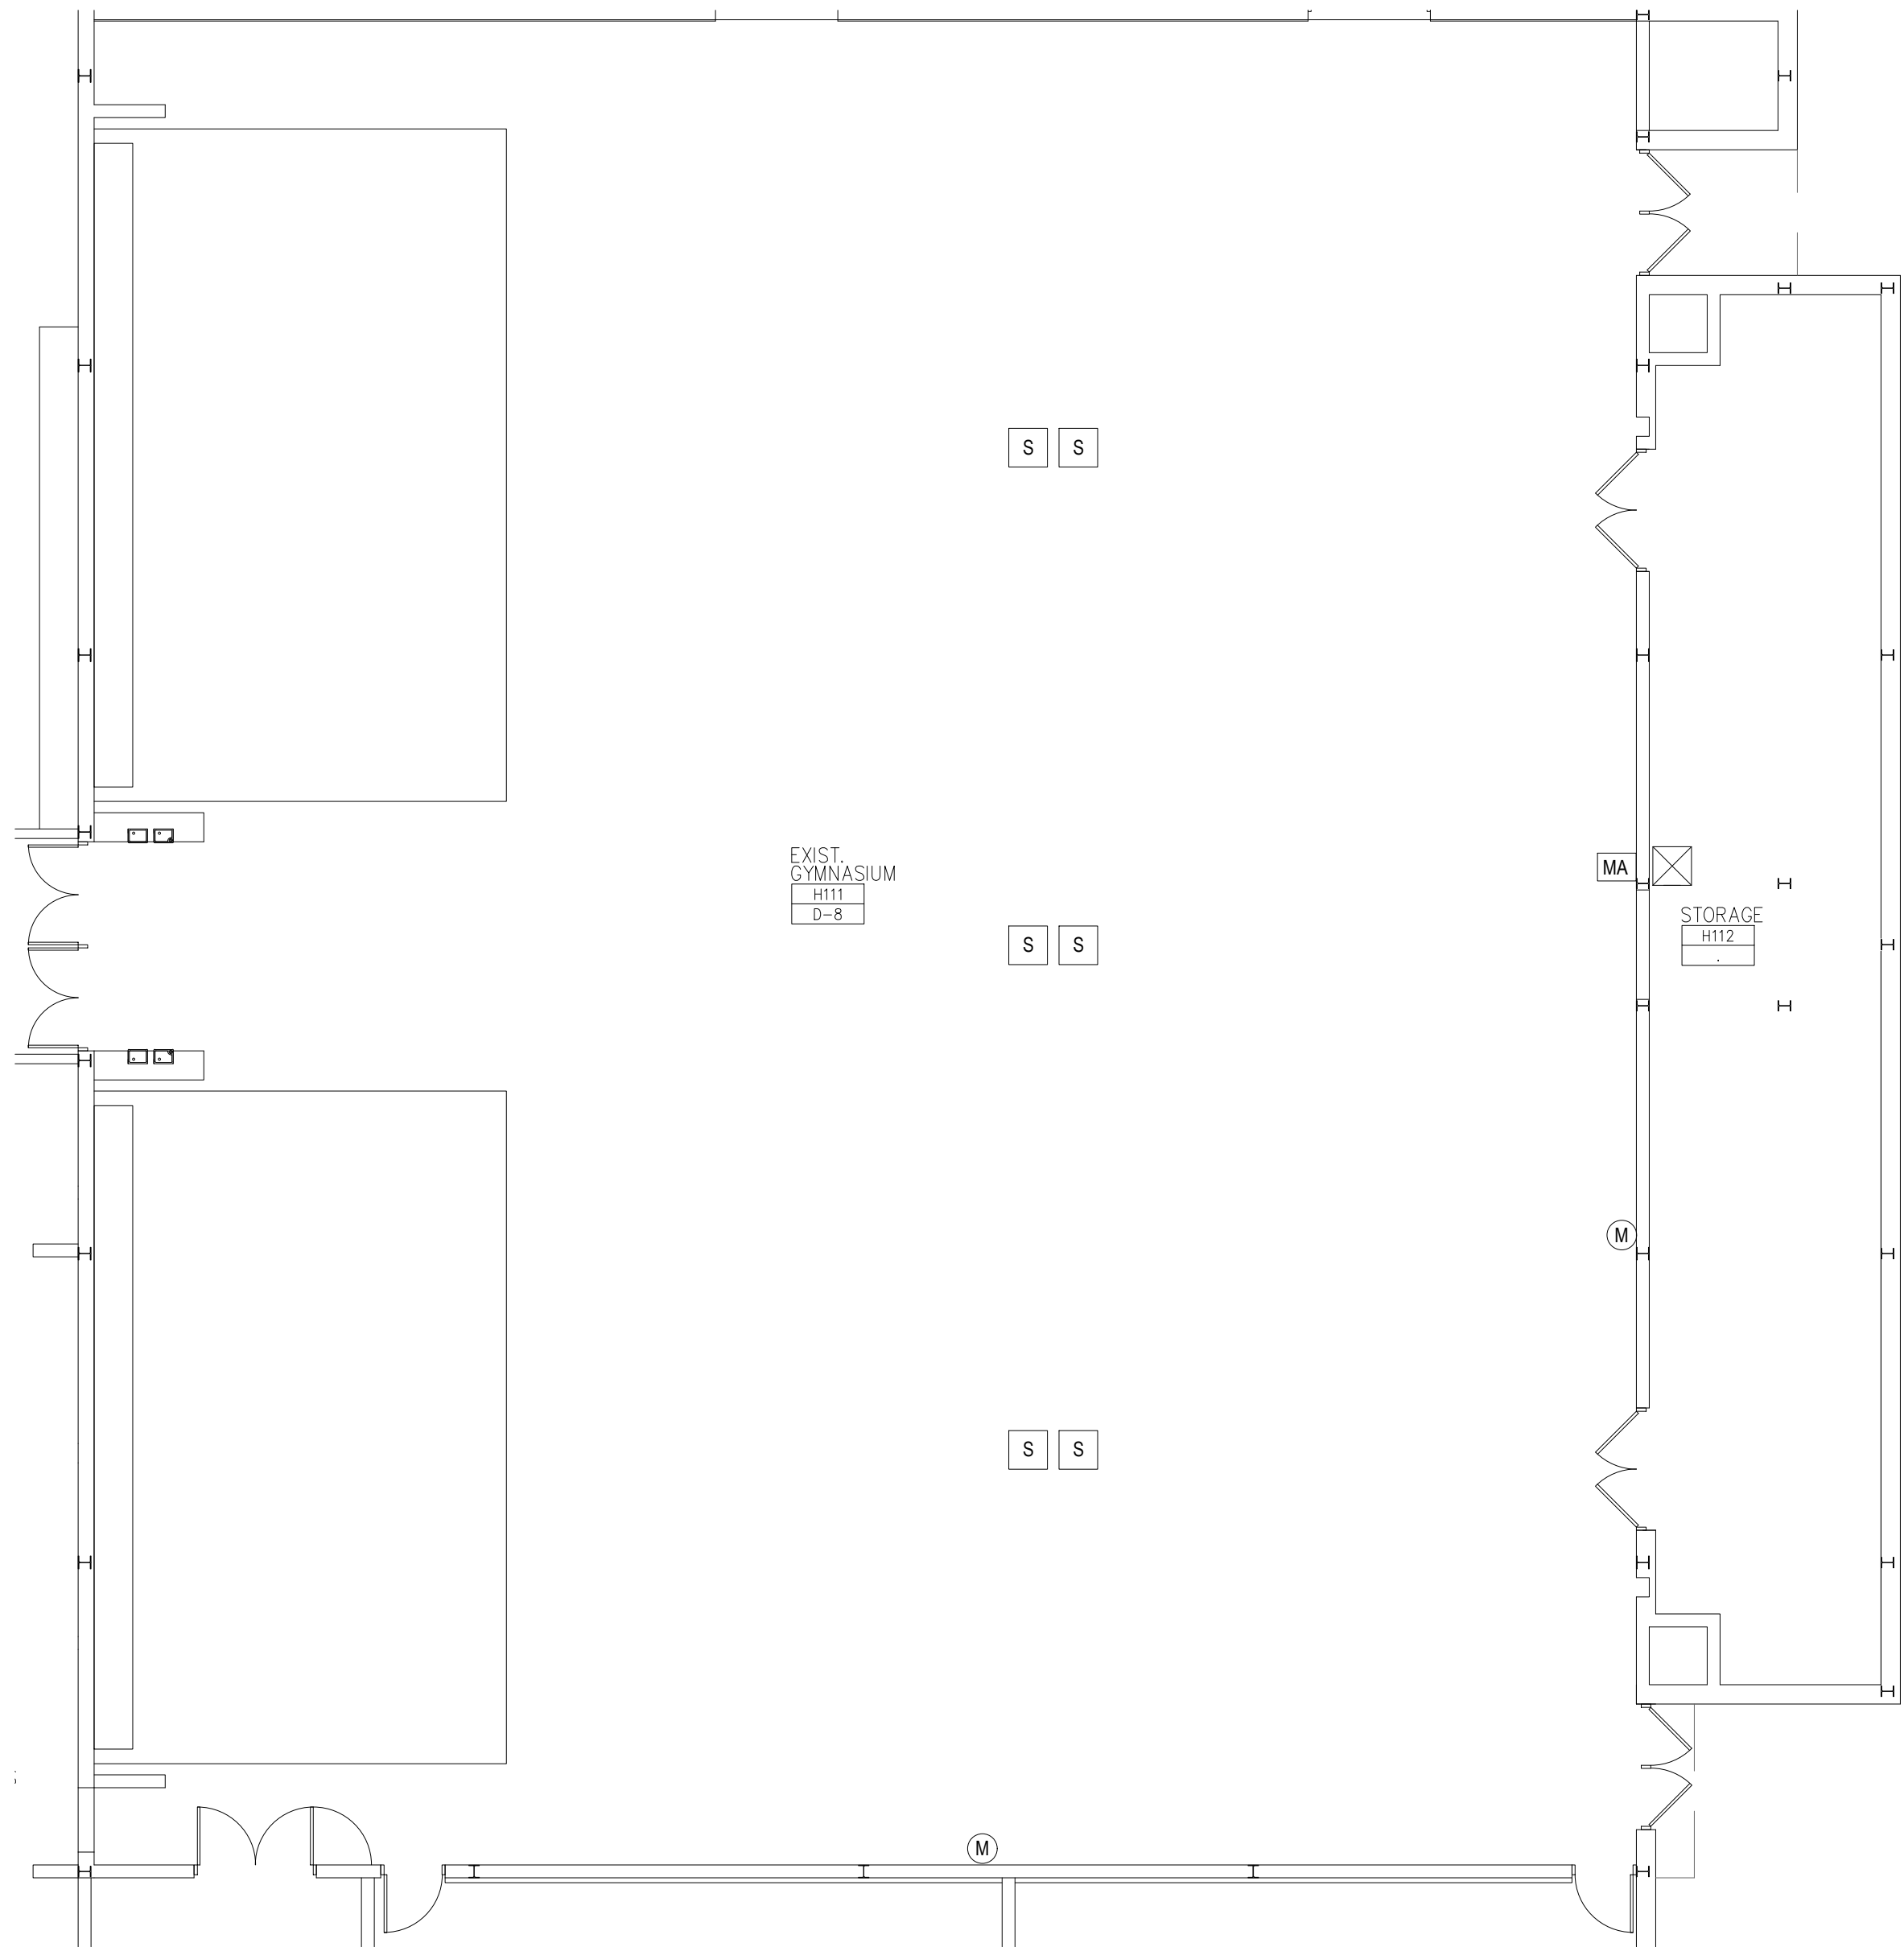

EXIST.
GYMNASIUM
HT11
D-8

MA

STORAGE
HT12

M

S S

S S

S S

1

GYMNASIUM AUDIO VIDEO SYSTEM


1/8" = 1'-0"

GENERAL AUDIO VIDEO NOTES:

1. FINAL LOCATIONS TO BE FIELD VERIFIED WITH OWNER PRIOR TO INSTALLATION.
2. PROVIDE SAFETY CABLES FOR ALL SPEAKERS.

AUDIO VIDEO FLOOR PLAN SYMBOL LEGEND:

- EC EQUIPMENT CABINET
- S SPEAKER
- M MICROPHONE
- MA MIC/AUX INPUT

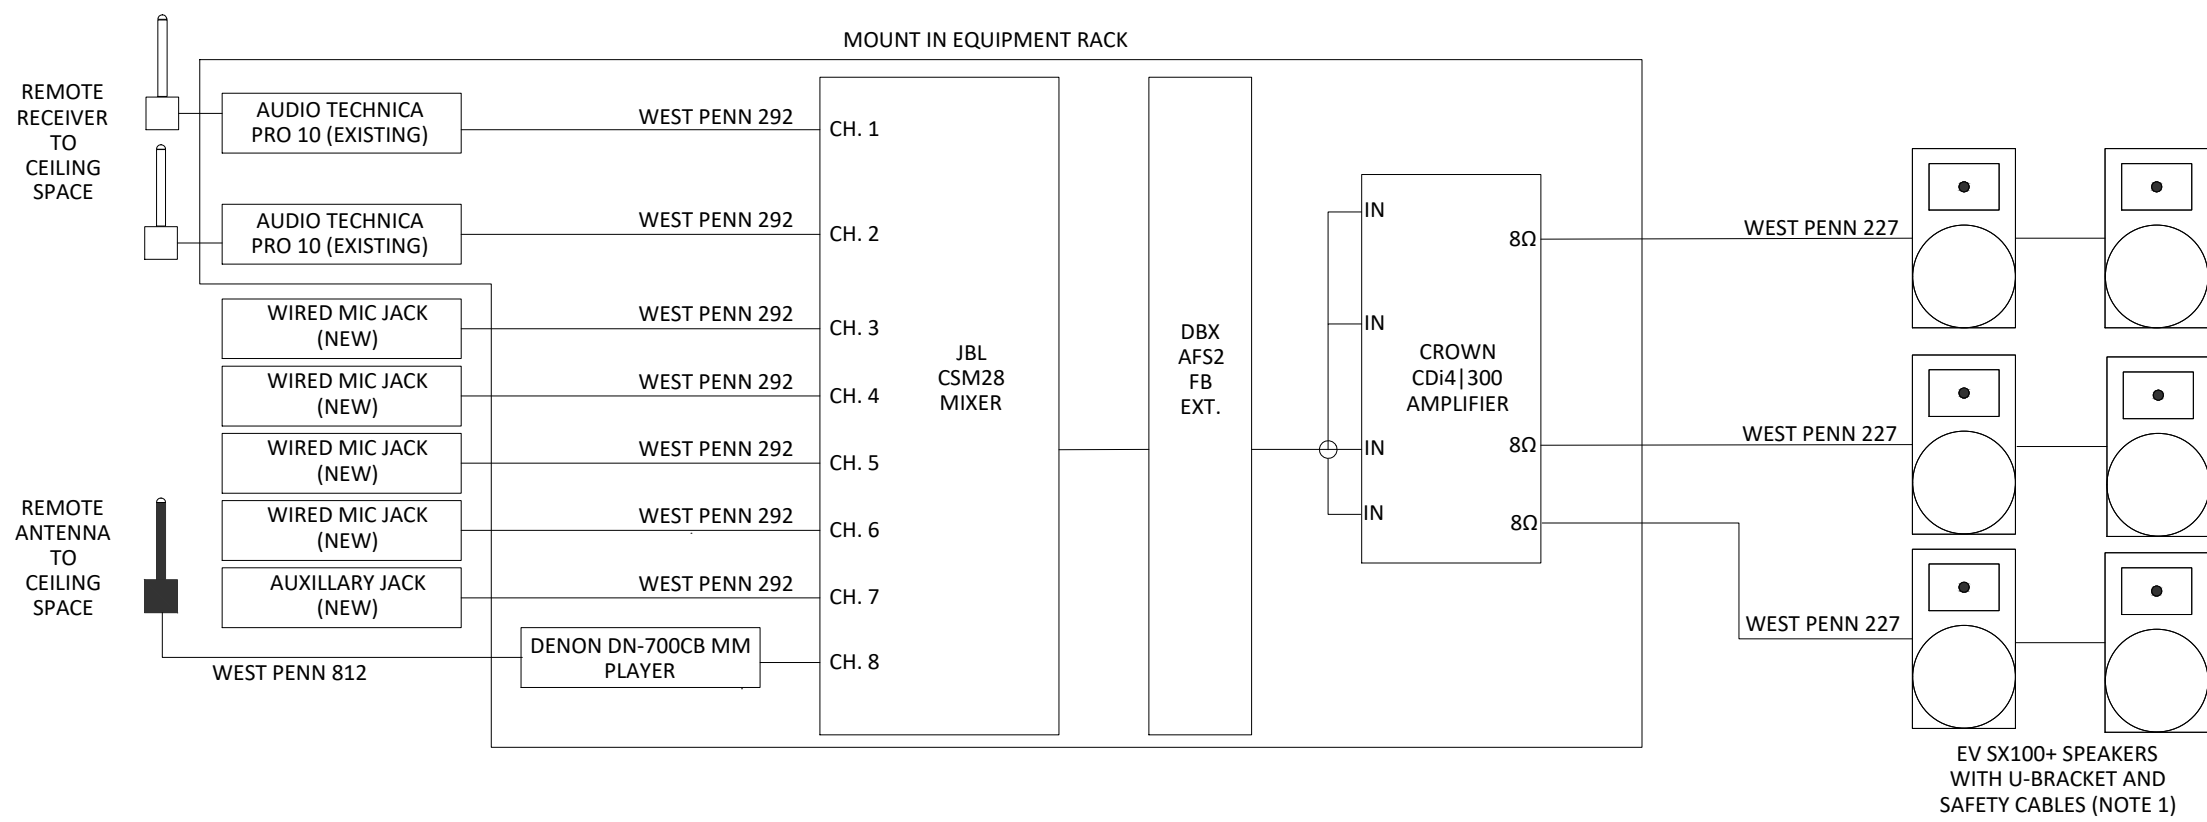

NOTES:

1. REMOVE EXISTING CEILING TILE SPEAKERS. NEW CEILING TILES TO BE FURNISHED BY OWNER.

KEY PLAN

OWNER

Northville Public
Schools

PROJECT NAME

Audio and Video Systems

Northville, MI 48167

PROJECT NO.

25-NPS-AVS-01

ISSUES / REVISIONS

03.12.2025 BIDS

DRAWN BY

BMJ

CHECKED BY

BG

APPROVED BY

SJB

SHEET NAME

MEADS MILL
MIDDLE SCHOOL
GYM AVS

SHEET NO.

TA116