



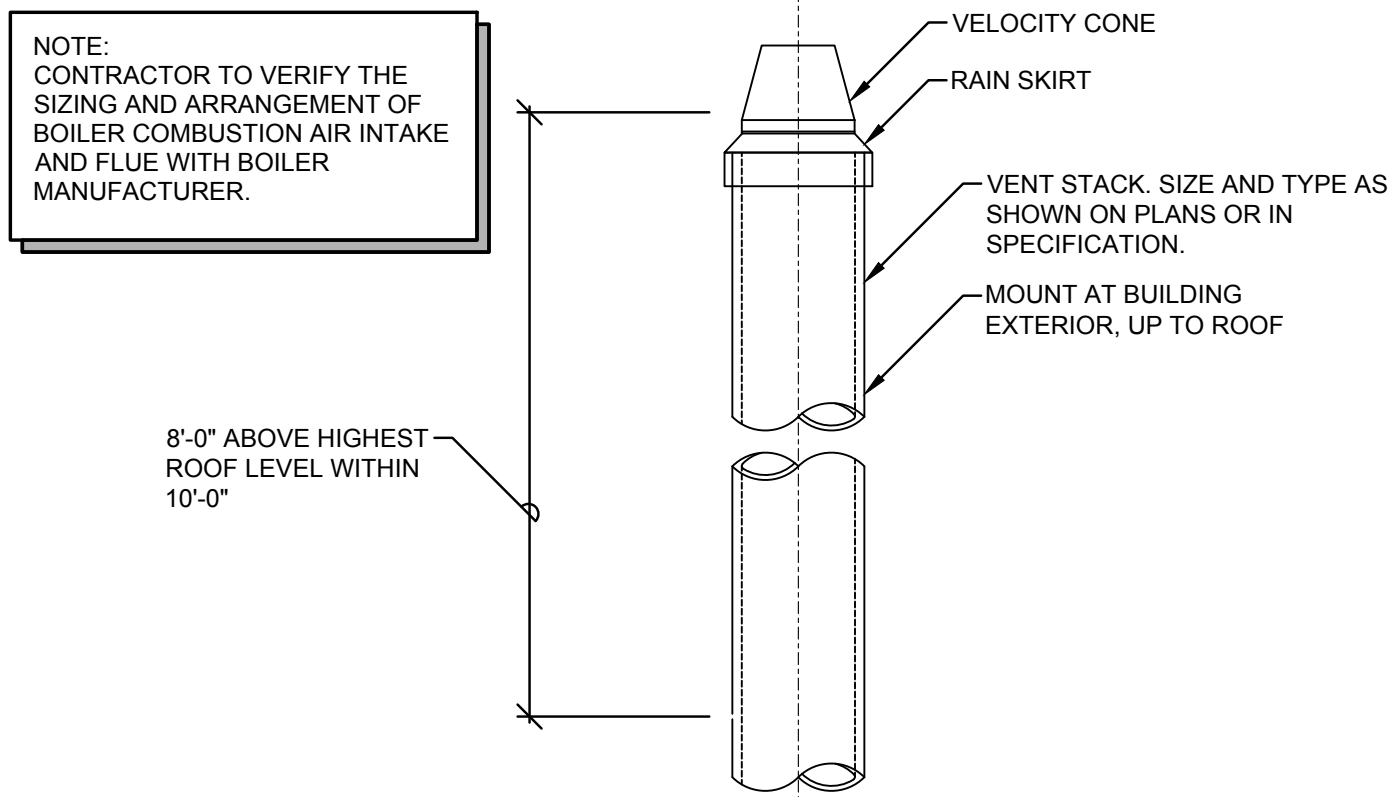


HOT WATER BOILER FLUE STACK DETAIL

NO SCALE

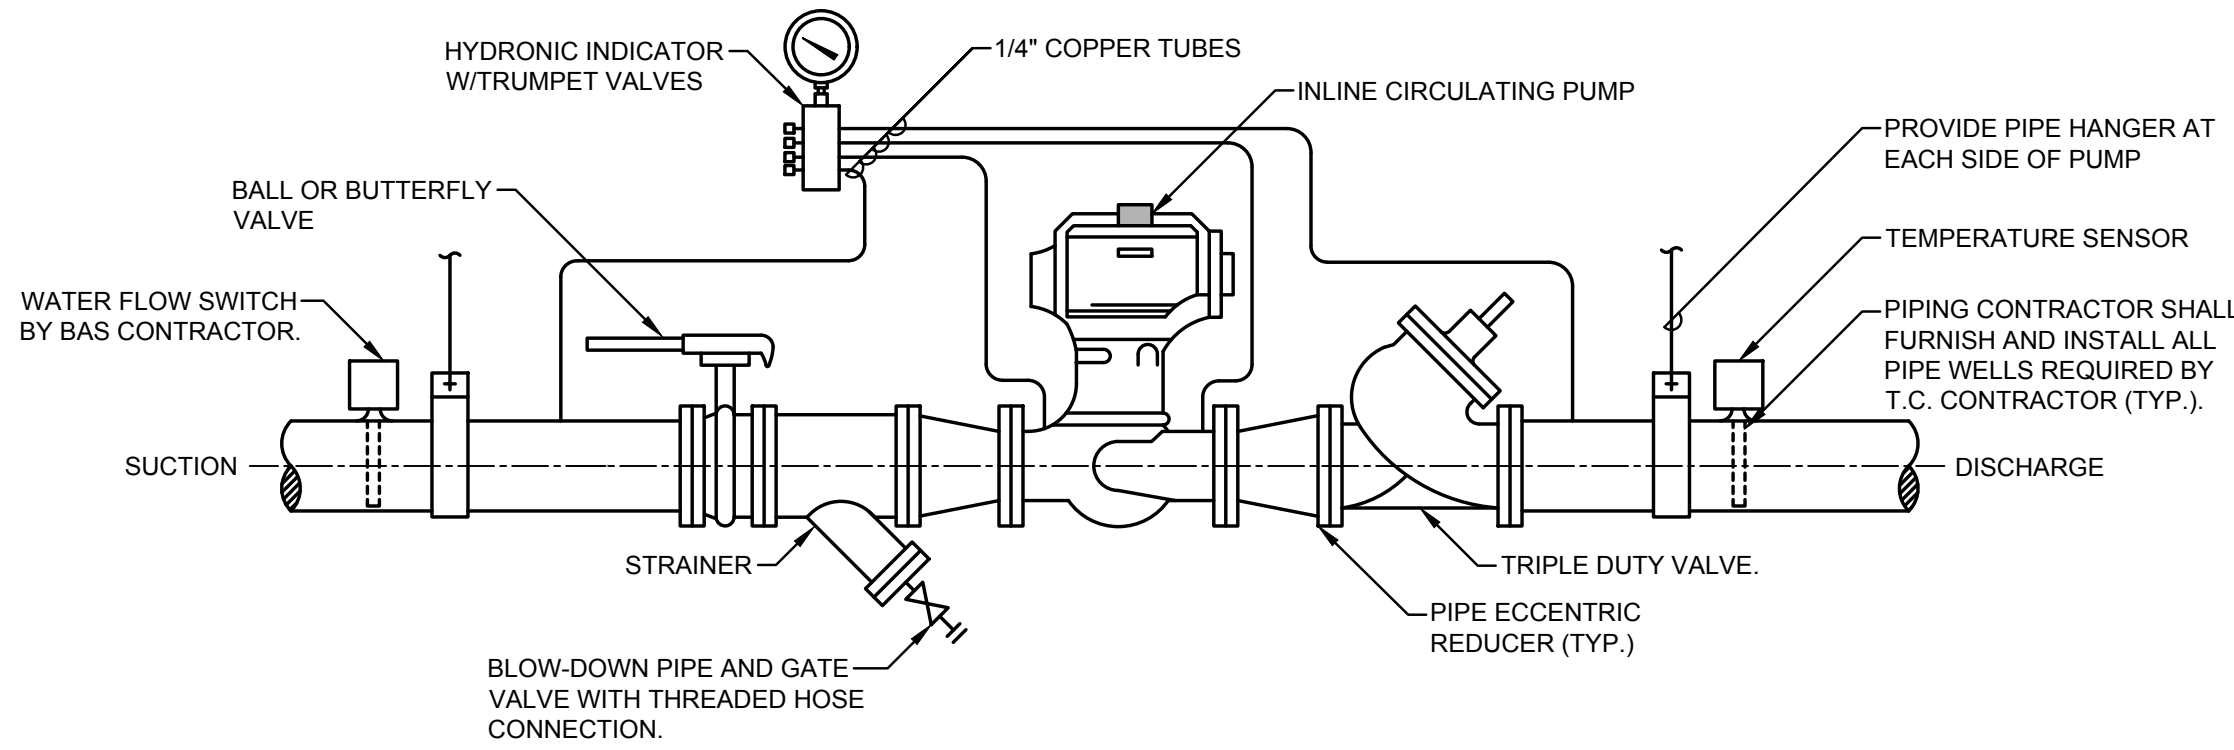


IN-LINE PUMP DETAIL

NO SCALE

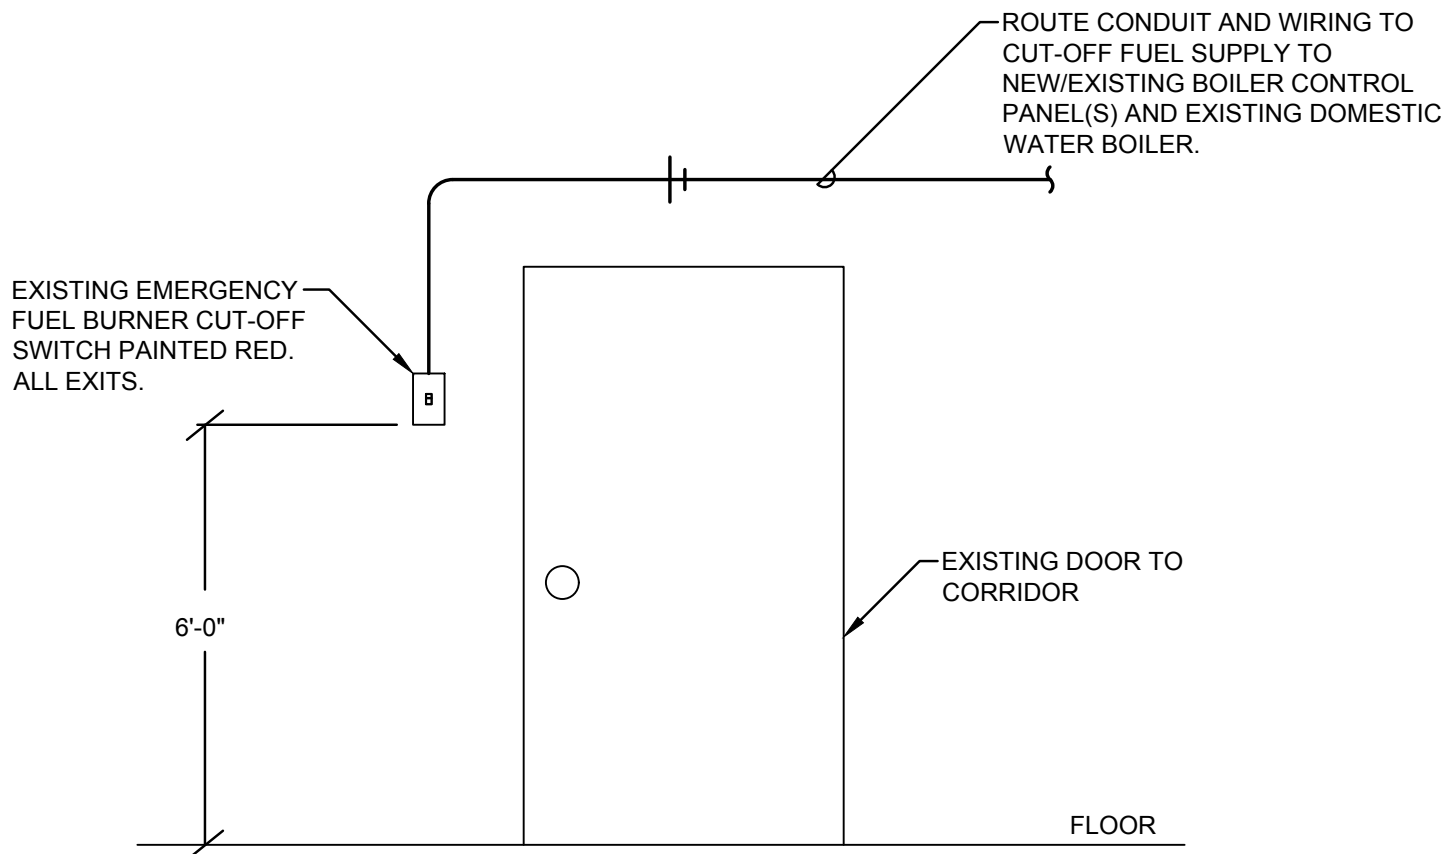


EMERGENCY FUEL BURNER CUT-OFF SWITCH DETAIL

NO SCALE

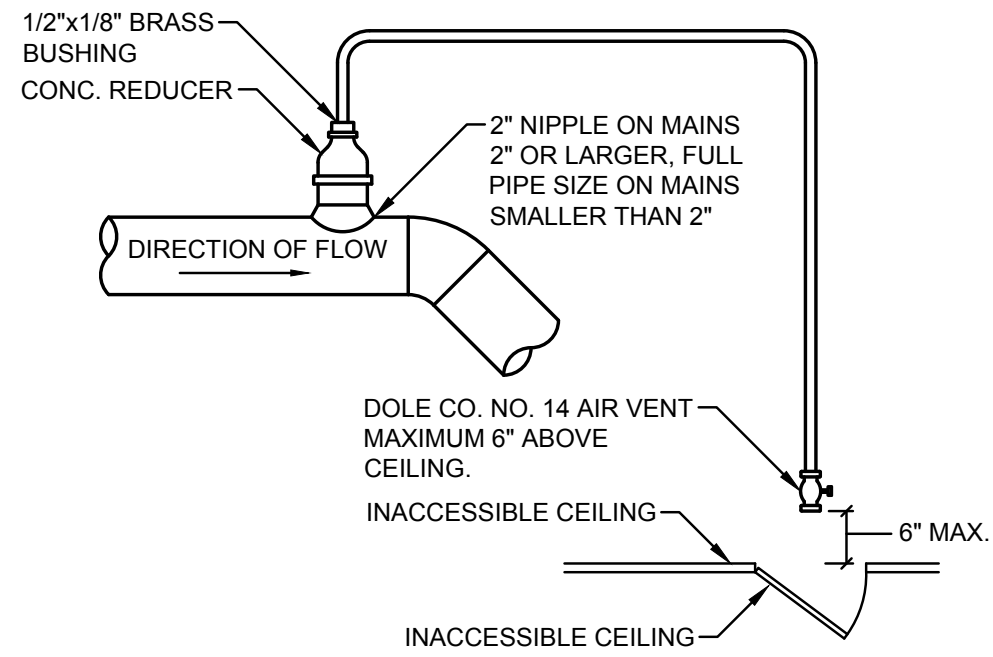

AIR VENT AT HIGH POINTS OF MAINS DETAIL

NO SCALE

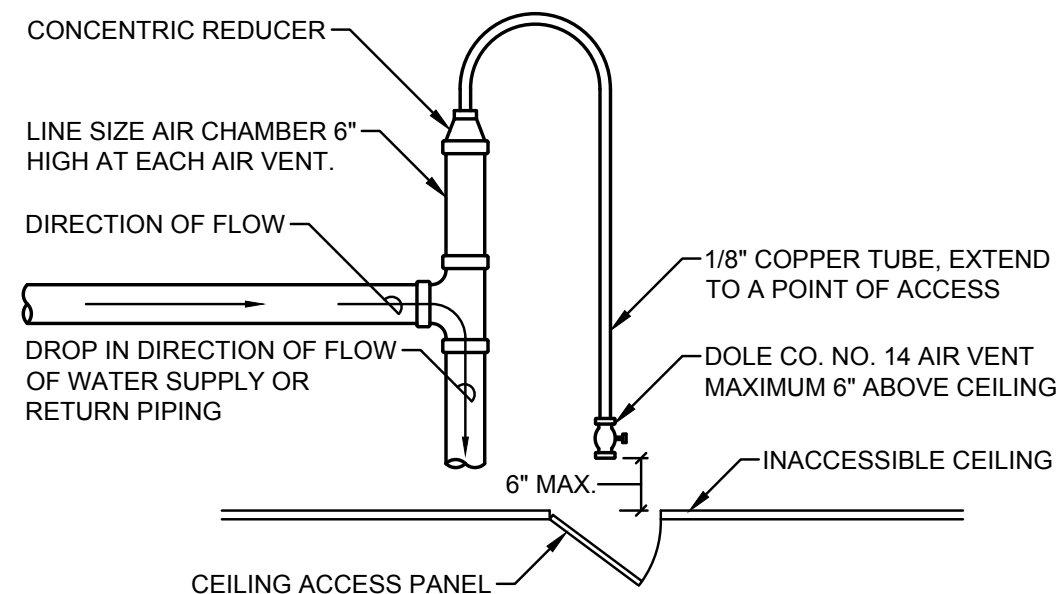

MANUAL AIR VENT DETAIL

NO SCALE

HVAC DETAILS

2025 HVAC UPGRADES
Murphy Elementary School, 220 Greenwood Dr, Round Lake Park, IL 60073
Round Lake Middle School, 2000 N Lotus Dr, Round Lake Heights, IL 60073
ROUND LAKE CUSD 116
510 N. CEDAR LAKE ROAD
ROUND LAKE, IL 60073

Issue Date:
18 SEP 2025
Drawn By:
CS2
Job Number:
886-S-1

HV3.2

COPYRIGHT © 2025
CS2 Design Group, LLC

OWNER REVIEW
NOT FOR CONSTRUCTION
09-18-2025