




GENERAL NOTES:

1. CONTRACTOR SHALL TOUCH UP PAINT TO MATCH EXISTING CONDITIONS FOR ALL AREAS OF NEW INSTALL OR DEMOLITION.
2. CONTRACTOR SHALL DEMO ALL SURFACE RACEWAY OR CONDUIT ABANDONED AS A RESULT OF DEMO.
3. AFTER CUTOVER TO NEW SYSTEMS, ALL ANALOG INTERCOM AND CLOCK CABLING SHALL BE DEMOED FROM ENDPOINT TO ENDPOINT, INCLUDING WITHIN CONDUITS AND PULL BOXES.


SHEET NOTES:

- 1 DEMO INTERCOM SPEAKER IN CEILING TILE AND CABLING TO SOURCE. PROVIDE REPLACEMENT CEILING TILE TO MATCH EXISTING.
- 2 DEMO EXTERIOR INTERCOM SPEAKER, BACKBOX, AND CABLE TO SOURCE. WATERPROOF ANY PENETRATIONS.
- 3 DEMO ANALOG TELEPHONE WALL PLATE, CABLING TO SOURCE, AND ABANDONED SURFACE RACEWAY.
- 4 DEMO TELECENTER HEADEND EQUIPMENT DELIVER HEADEND UNIT TO DISTRICT ELECTRONICS SHOP.
- 5 DEMO CLOCK POWER SUPPLY AND SAFE OFF POWER.
- 6 DEMO CRT TV AND WALL MOUNT BRACKET.
- 7 DEMO ABANDONED AP MOUNT BRACKET AND CABLING, AS OCCURS.
- 8 DEMO COAX PLATE AND CABLE TO SOURCE. PROVIDE BLANK PLATE AS REQ'D.
- 9 DEMO ABANDONED DATA DROP AND CABLE TO SOURCE.

PICTURE DETAIL
- TELECENTER HEADEND DEMO

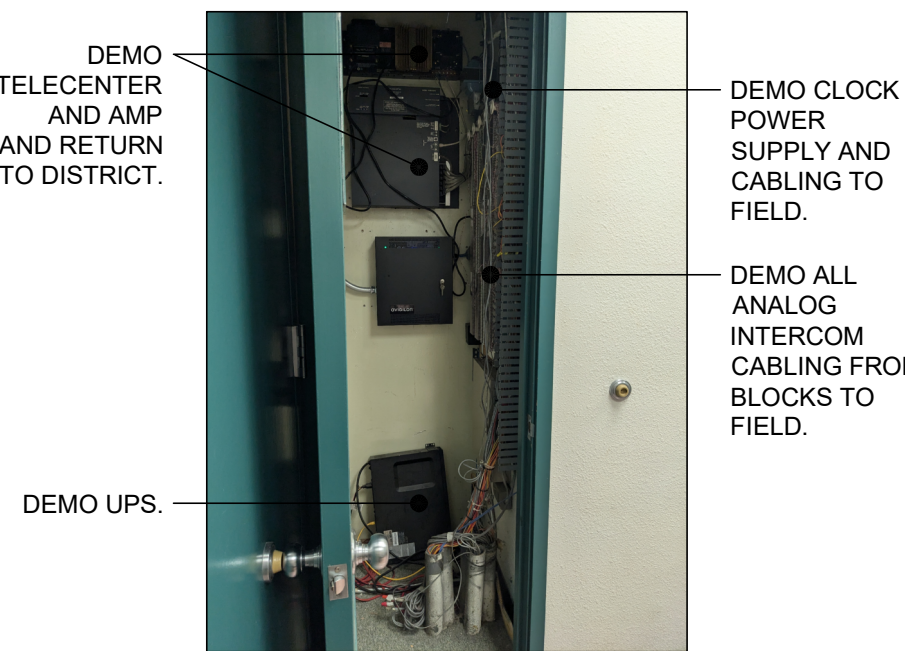

PICTURE DETAIL
- MPOE ROOM DEMO

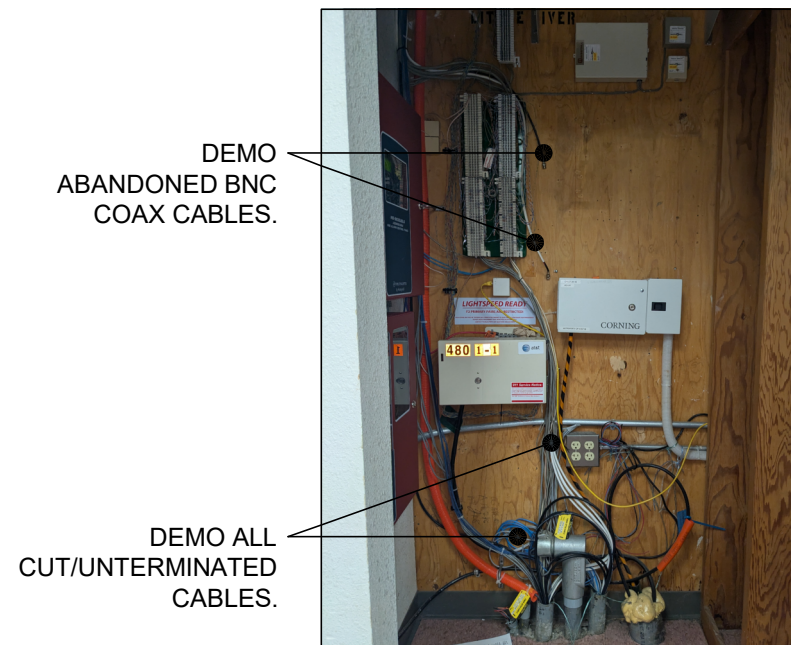

KMM SERVICES, INC
TECHNOLOGY & FIRE LIFE SAFETY

5433 El Camino Ave. Suite 5
Carmichael, CA 95608
Office: (916) 359-4000 www.kmm-services.com

LICENSE STAMPS



Copyright © 2025

These drawings and specifications and the ideas, designs and arrangements represented thereby are not shall remain the property of KMM Services, Inc. and no part thereof shall be copied, disclosed to others, or used in connection with any other work or project other than the specific project for which they have been prepared and developed without the written consent of KMM Services, Inc. Visual contact with these drawings or specifications shall constitute conclusive evidence of these restrictions.

IF DRAWING IS NOT 30"x42" IT IS A REDUCED PRINT

SHEET REVISIONS

DELTA	DESCRIPTION	DATE
ADD-001		2025-11-13

SITE KEY PLAN

PROJECT
SACRAMENTO CITY
UNIFIED SCHOOL DISTRICT
MARTIN LUTHER KING JR.
TELECENTER UPGRADE
480 LITTLE RIVER WAY
SACRAMENTO, CA 95831

SHEET TITLE
TECHNOLOGY
SITE PLAN - DEMO

DRAWING STATUS
CONSTRUCTION DOCUMENTS

PROJECT NO:	-
BID PACKAGE:	-
DESIGNED BY:	-
CHECKED BY:	-
ISSUE DATE:	2025-10-13
WORKING DATE:	2025-11-13

REVISION


SHEET

T010

TECHNOLOGY SITE PLAN - DEMO

SCALE: 1"=20'



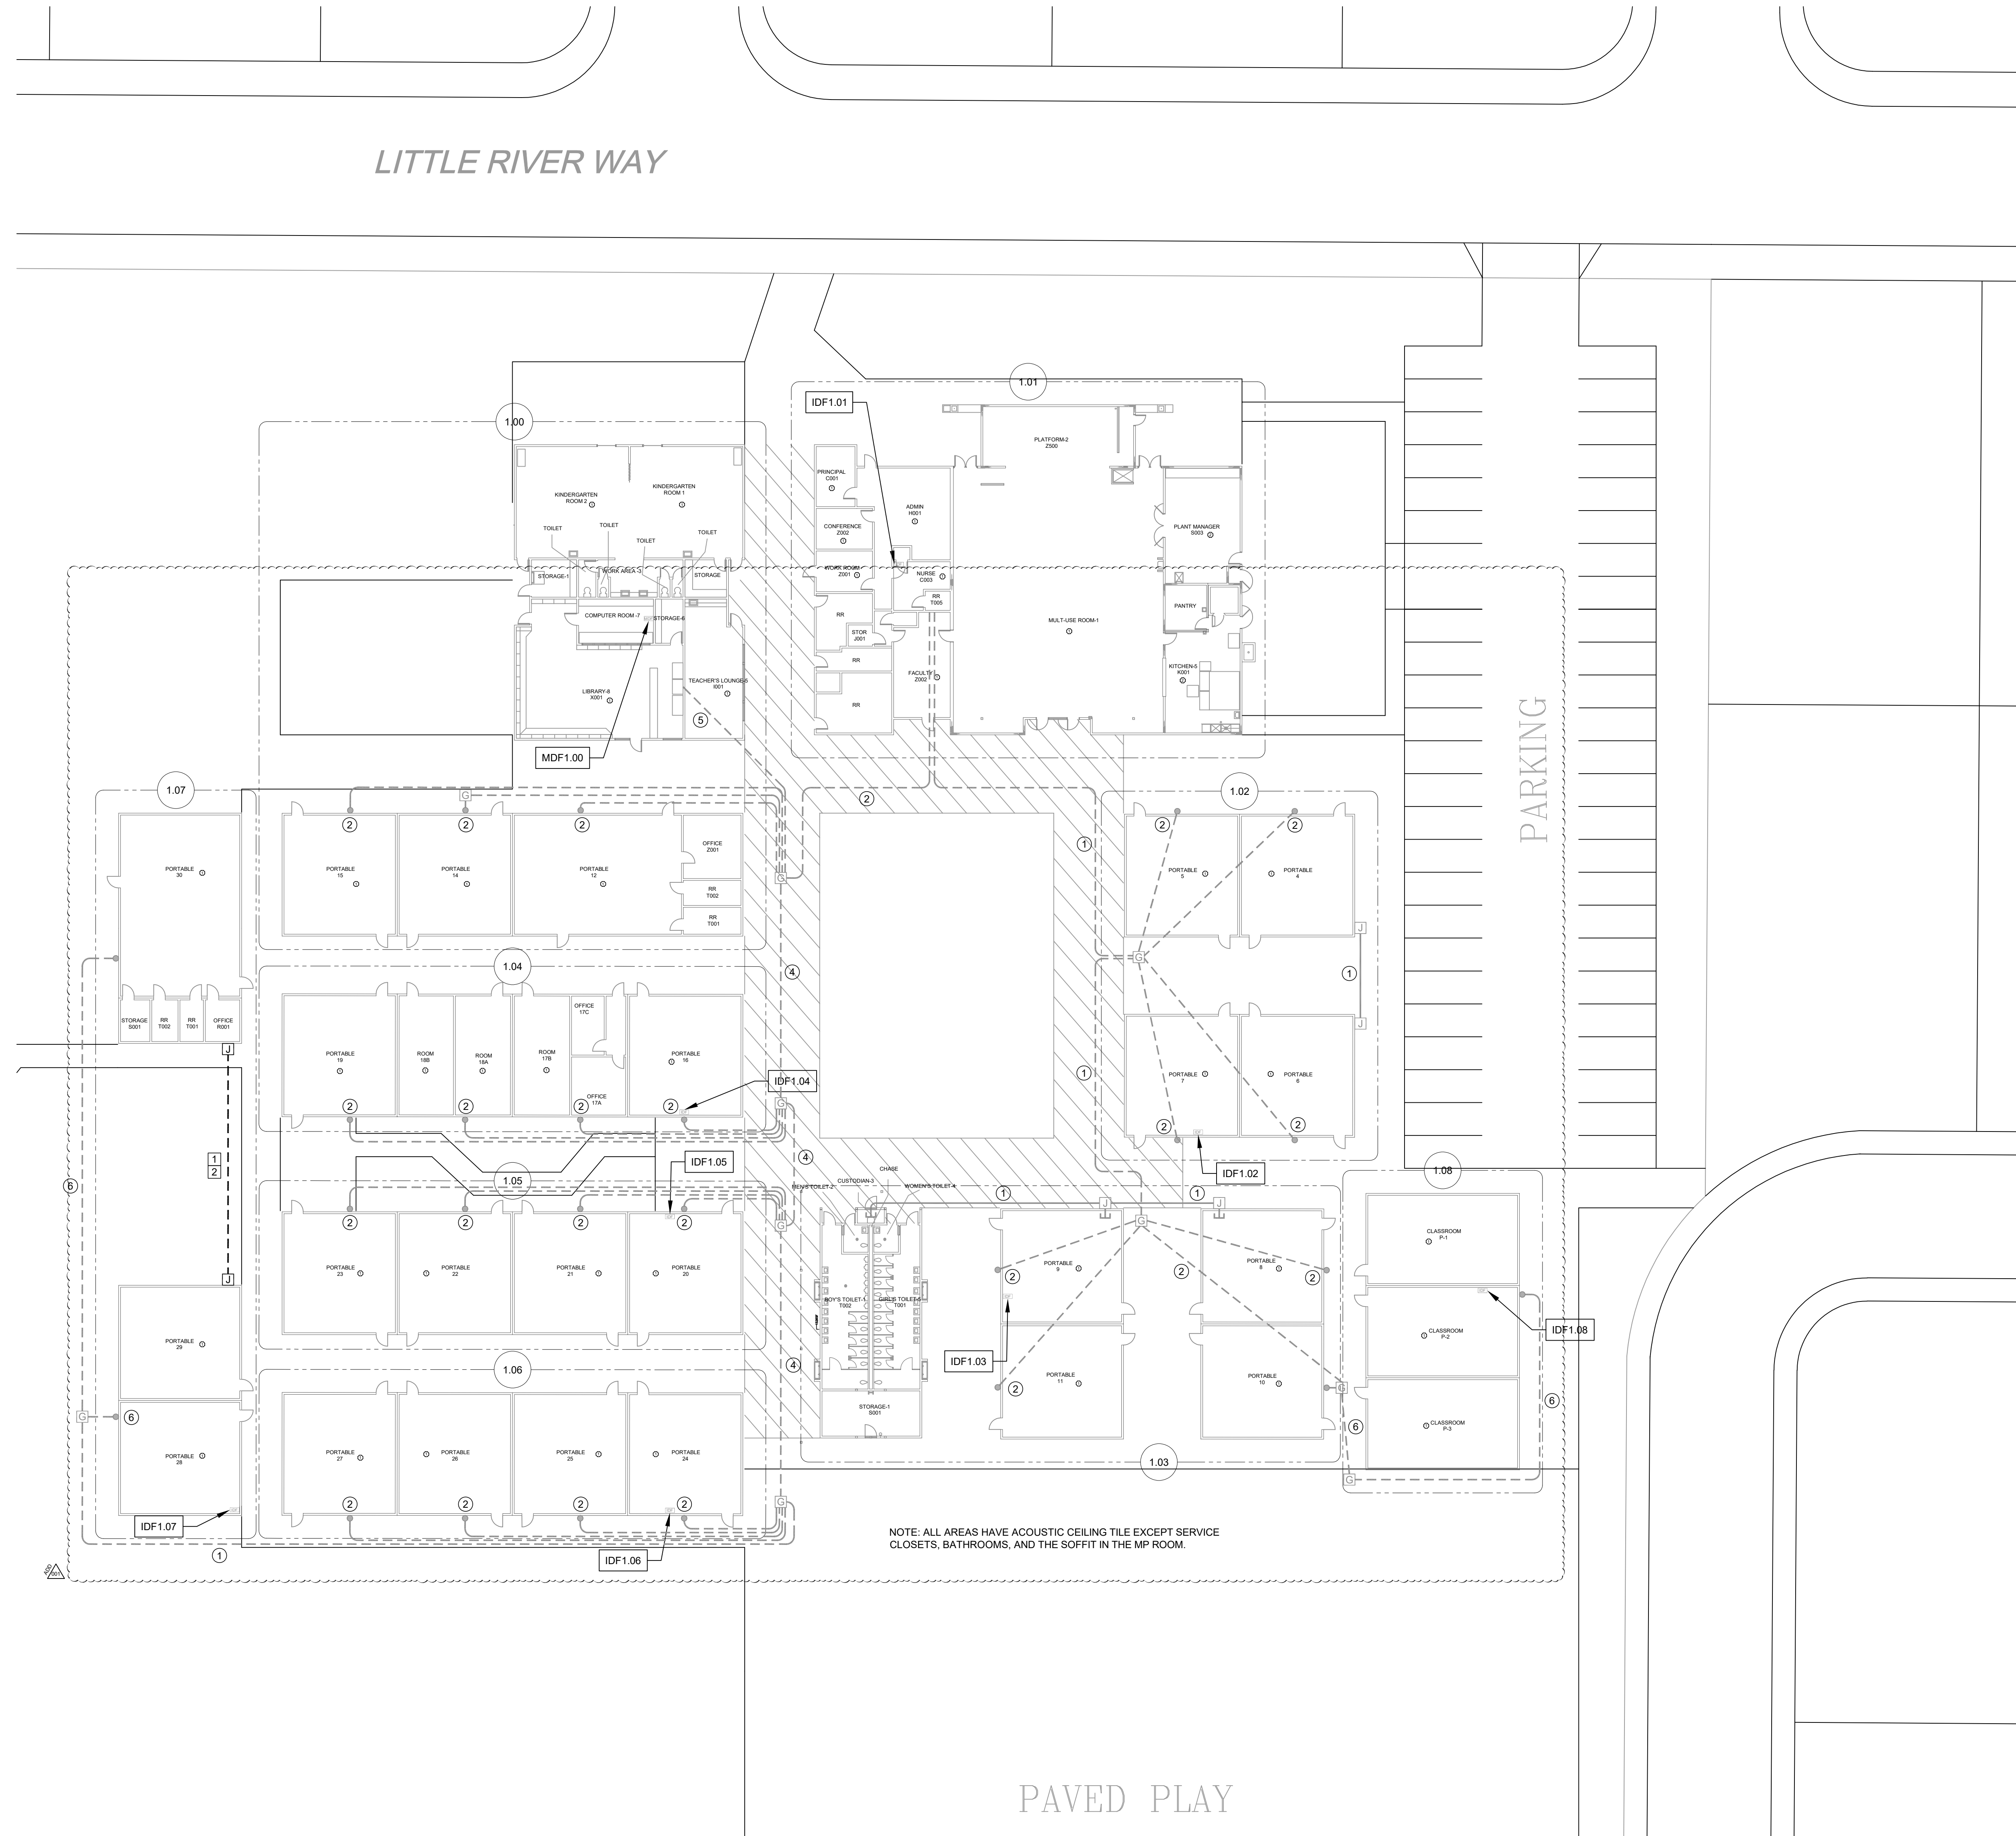

1. NO STRUCTURAL BEAMS SHALL BE PENETRATED OR ALTERED.
2. ALL EQUIPMENT AND MATERIALS ARE CONTRACTOR FURNISHED, INSTALLED, AND CONFIGURED, UNO.
3. CONTRACTOR SHALL TOUCH UP PAINT TO MATCH EXISTING CONDITIONS FOR ALL AREAS OF NEW INSTALL OR DEMOLITION.
- SHEET NOTES:
- 1 BORE OR TRENCH NEW CONDUIT. SAWCUT AND PATCH CONCRETE SIDEWALK.
- 2 (N) 1 EA. 2" CONDUITS.



KMM SERVICES, INC
TECHNOLOGY & FIRE LIFE SAFETY

5433 El Camino Ave., Suite 5
Carmichael, CA 95608
Office: (916) 359-4000 www.kmm-services.com

LICENSE STAMPS



Copyright © 2025
These drawings and specifications and the ideas, designs and arrangements represented thereby are and shall remain the property of KMM Services, Inc. and no part thereof shall be copied, disclosed to others, or used in connection with any other work or project other than the specific project for which they have been prepared and developed without the written consent of KMM Services, Inc. Visual contact with these drawings or specifications shall constitute conclusive evidence of these restrictions.

IF DRAWING IS NOT 30"X42" IT IS A REDUCED PRINT

SHEET REVISIONS

DELTA	DESCRIPTION	DATE
ADD-001		2025-11-13

SITE KEY PLAN

PROJECT
SACRAMENTO CITY
UNIFIED SCHOOL DISTRICT
MARTIN LUTHER KING JR.
TELECENTER UPGRADE
480 LITTLE RIVER WAY
SACRAMENTO, CA 95831


SHEET TITLE
TECHNOLOGY
SITE PLAN - NEW

DRAWING STATUS
CONSTRUCTION DOCUMENTS

PROJECT NO:	-
BID PACKAGE:	-
DESIGNED BY:	-
CHECKED BY:	-
ISSUE DATE:	2025-10-13
WORKING DATE:	2025-11-13

REVISION

SHEET
T100

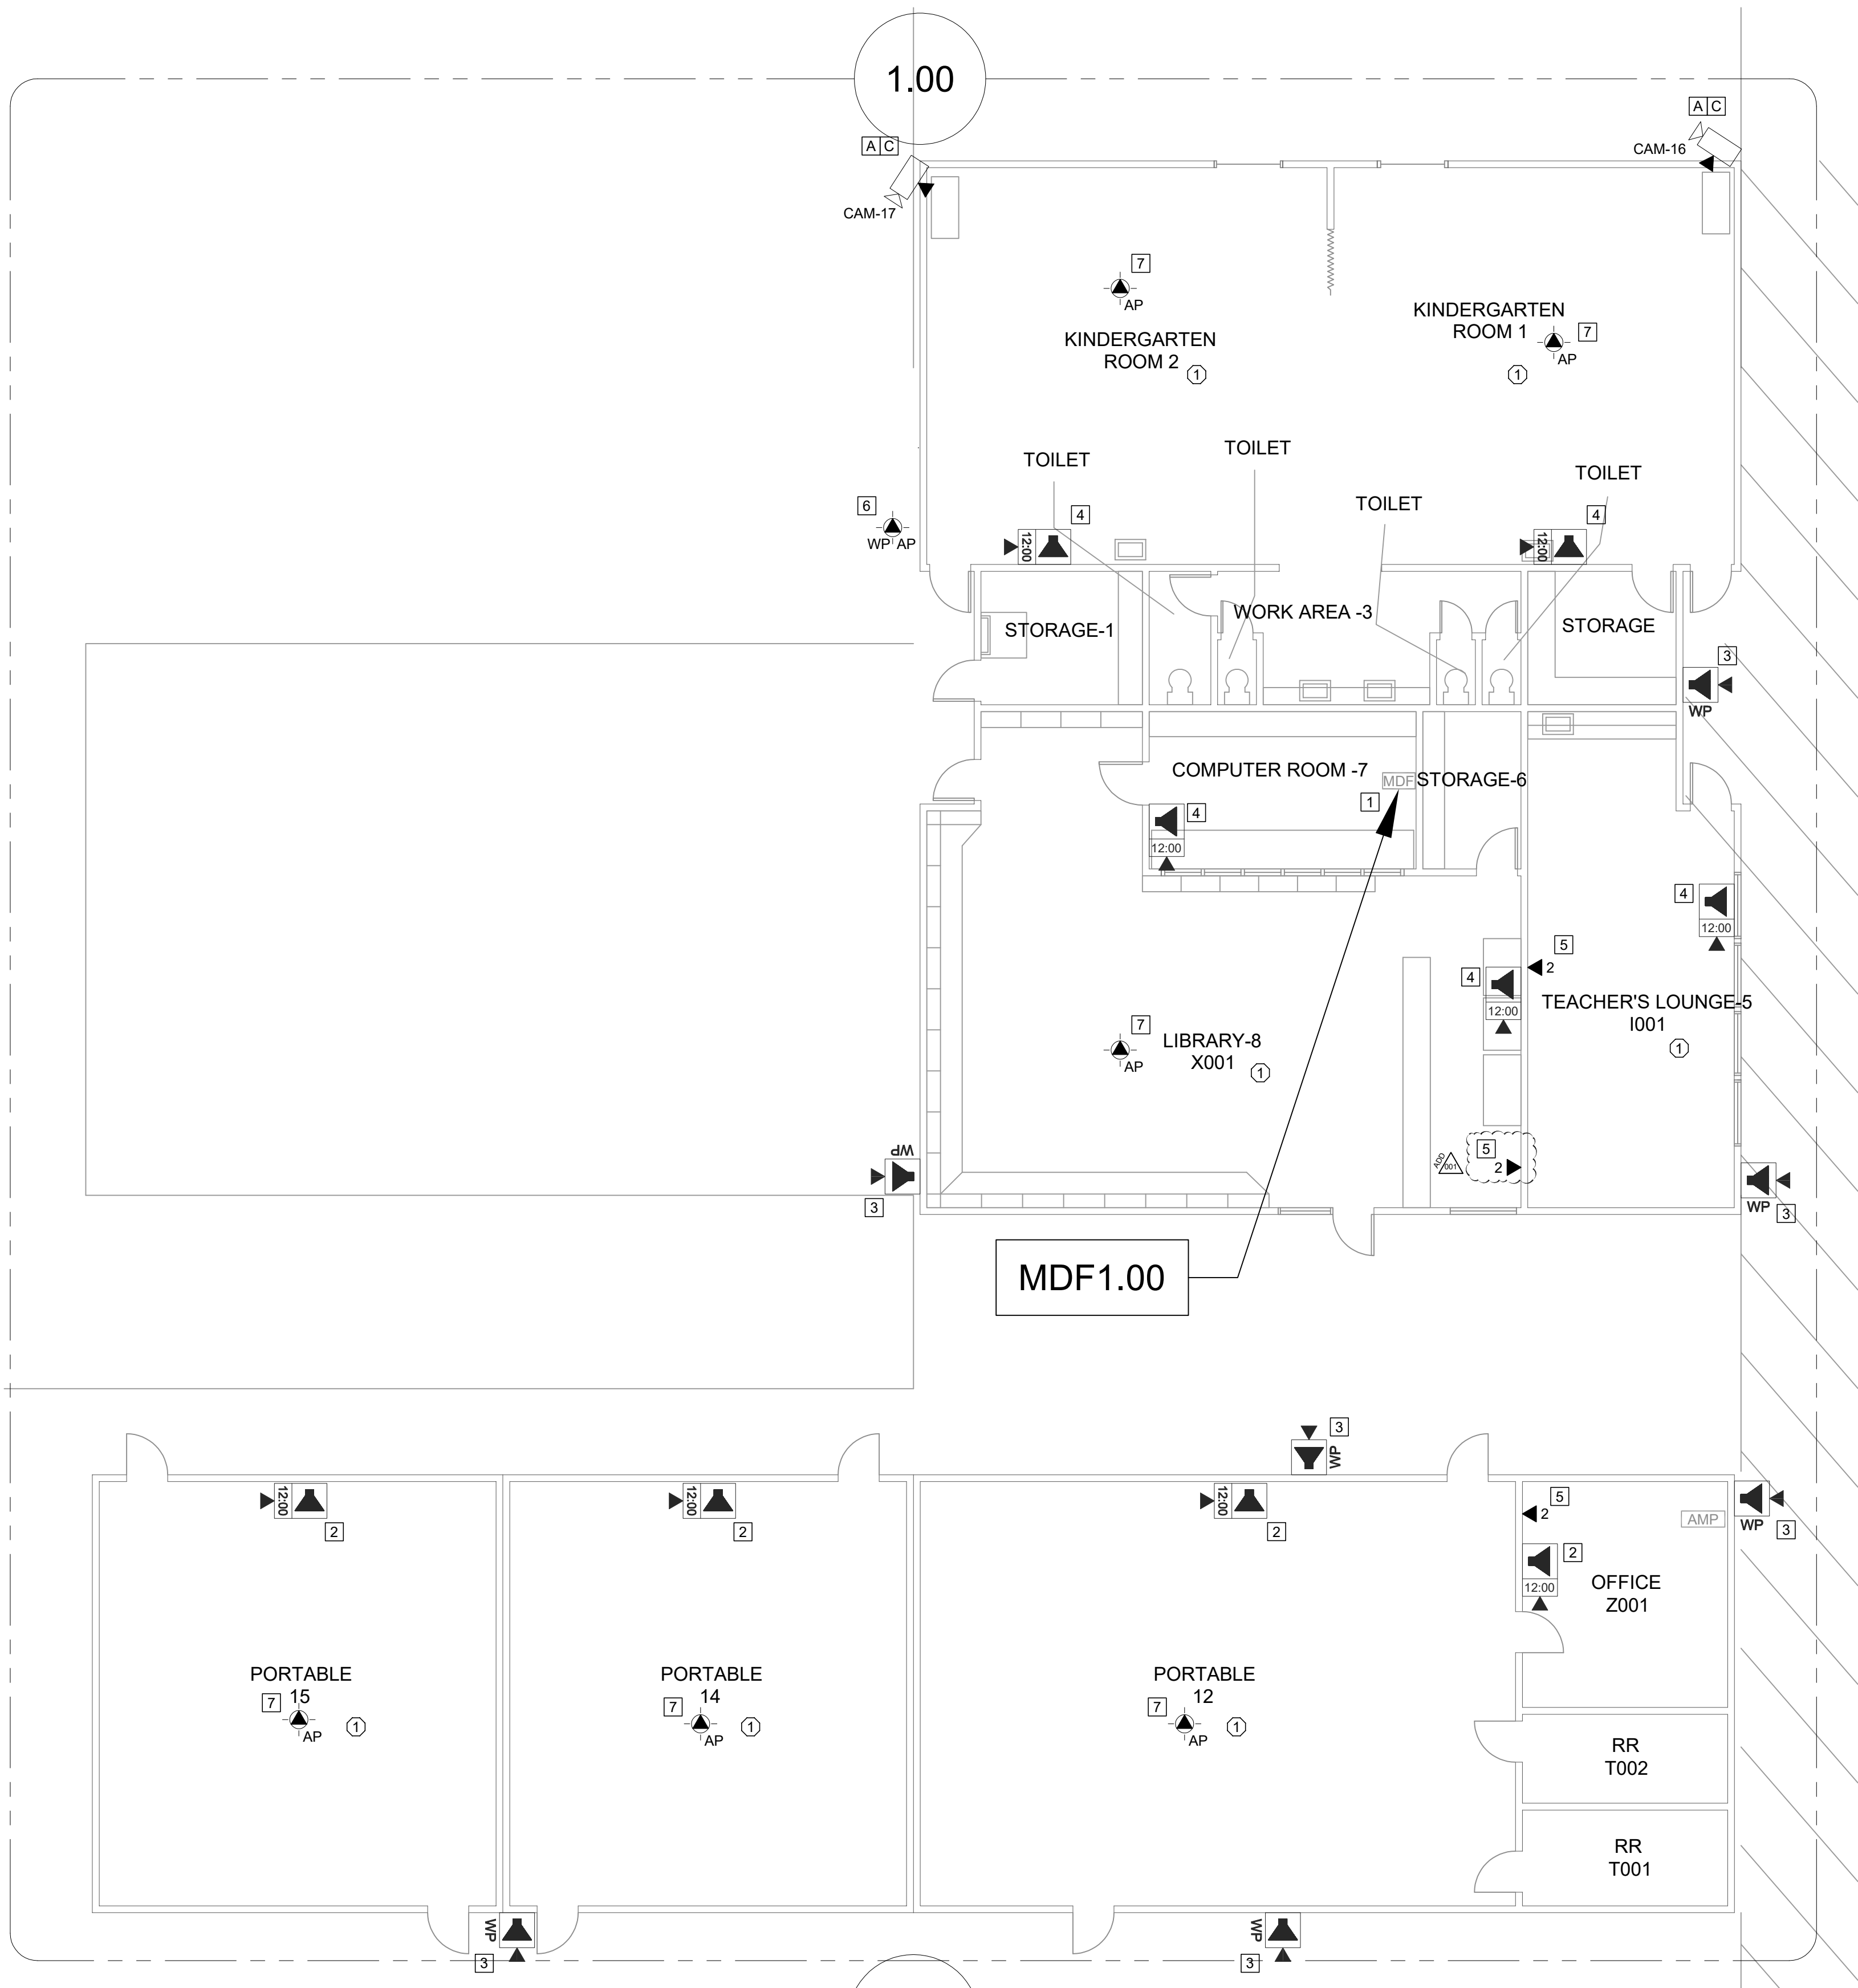

TECHNOLOGY FLOOR PLAN NEW - MDF 1.00

SCALE: 1/8"=1'

0 4 8 12 16


CEILING CONDITION CHART:
① DROP IN CEILING TILES.
② HARD LID CEILING.

GENERAL NOTES:
1. NO STRUCTURAL BEAMS SHALL BE PENETRATED OR ALTERED.
2. ALL EQUIPMENT AND MATERIALS ARE CONTRACTOR FURNISHED, INSTALLED, AND CONFIGURED, UNO.
3. CONTRACTOR SHALL TOUCH UP PAINT TO MATCH EXISTING CONDITIONS FOR ALL AREAS OF NEW INSTALL OR DEMOLITION.

CCTV GENERAL NOTES:
1. ALL (N) EXTERIOR DOME CAMERAS MOUNTED TO WALL SURFACE SHALL HAVE A SUN SHADE INSTALLED.
2. SEE SHEETS T801 AND T900 FOR CAMERA DETAILS.


SHEET NOTES:
[A] PROVIDE (N) EXTERIOR NETWORK SECURITY CAMERA. PROVIDE (N) BACK BOX AS REQUIRED. PROVIDE (N) 1 EA. CAT6A DATA DROP. [B] MOUNT (N) CAMERA ON WALL AT BUILDING CORNER. [C] MOUNT (N) CAMERA UNDER CANOPY AT BUILDING CORNER. [D] MOUNT (N) CAMERA ON BEAM UNDER CANOPY. PROVIDE APPROX. 20' CONDUIT PATHWAY FROM (N) CAMERA DEVICE TO (E) JUNCTION BOX. [1] REWORK MDF/IDF PER RACK ELEVATION. SEE T400/T401. [2] REMOVE (E) CLOCK/SPEAKER AS OCCURS. PROVIDE (N) COMBO BOX WITH (N) SPEAKER, (N) CLASSROOM IP MODULE, AND (N) IP CLOCK. PROVIDE (N) 1 EA. CAT6A DATA DROP. FISH THROUGH WALL TO (N) CUT-IN BOX BEHIND COMBO BACKBOX. [3] PROVIDE (N) EXTERIOR SPEAKER WITH (N) EXTERIOR BACKBOX. PROVIDE (N) INTERIOR ENCLOSURE WITH (N) CLASSROOM IP MODULE. PROVIDE (N) 1 EA. CAT6A DATA DROP AT INTERIOR ENCLOSURE. [4] REMOVE (E) CLOCK/SPEAKER COMBO BAFFLE. PROVIDE (N) RETROFIT BAFFLE WITH (N) SPEAKER, (N) CLASSROOM MODULE, AND (N) IP CLOCK. NOTCH CENTER DIVIDER OF (E) BACKBOX TO ACCOMMODATE CLOCK. PROVIDE (N) 1 EA. CAT6A DATA DROP AND ROUTE INTO (E) BACKBOX VIA (E) CONDUIT STUB TO ACCESSIBLE CEILING. [5] PROVIDE (N) CAT6A DATA DROP. QUANTITY INDICATED. CUT IN AND FISH THROUGH WALL TO ACCESSIBLE CEILING. [6] REWORK (E) DATA DROP AT EXTERIOR AP AND PROVIDE REQUIRED COMPONENTS PER DETAIL 12/T801, 13/T801. [7] INSTALL (N) OWNER-FURNISHED WIRELESS AP AT (E) AP DATA DROP LOCATION. REMOVE (E) WIRELESS AP, AS OCCURS.

KEY PLAN

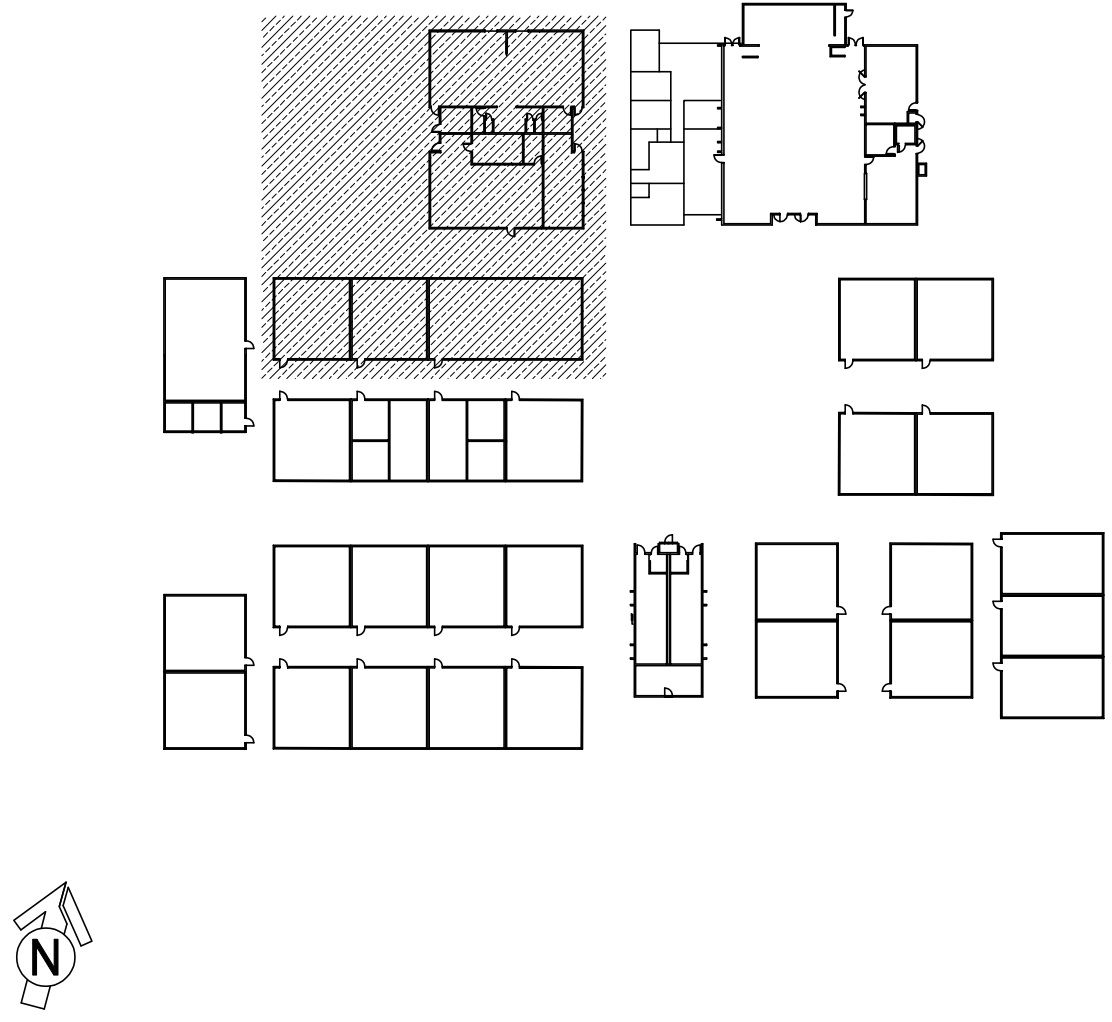

KMM SERVICES, INC
TECHNOLOGY & FIRE LIFE SAFETY

5433 El Camino Ave. Suite 5
Carmichael, CA 95608
Office: (916) 359-4000 www.kmm-services.com

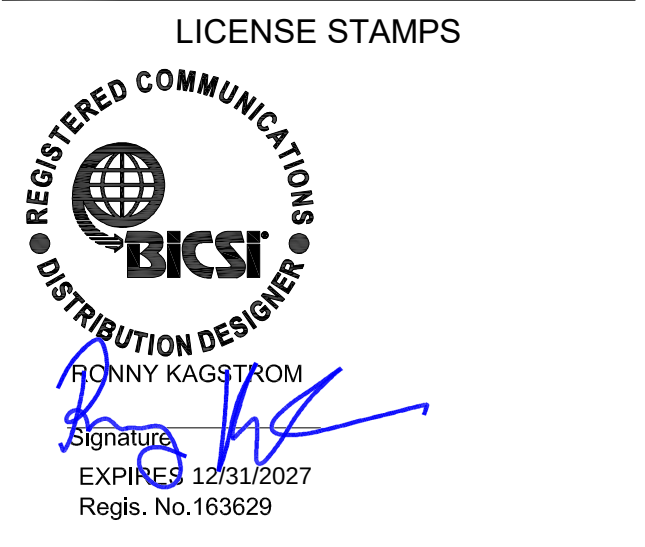

Copyright © 2025
These drawings and specifications and the ideas, designs and arrangements represented thereby are and shall remain the property of KMM Services, Inc. and no part thereof shall be copied, disclosed to others, or used in connection with any other work or project other than the specific project for which they have been prepared and developed without the written consent of KMM Services, Inc. Visual contact with these drawings or specifications shall constitute conclusive evidence of these restrictions.

IF DRAWING IS NOT 30"X42" IT IS A REDUCED PRINT

SHEET REVISIONS		
DELTA	DESCRIPTION	DATE
ADD-001		2025-11-13

SITE KEY PLAN


PROJECT
SACRAMENTO CITY
UNIFIED SCHOOL DISTRICT
MARTIN LUTHER KING JR.
TELECENTER UPGRADE
480 LITTLE RIVER WAY
SACRAMENTO, CA 95831

SHEET TITLE
TECHNOLOGY
FLOOR PLAN -
MDF 1.00

DRAWING STATUS
CONSTRUCTION DOCUMENTS

PROJECT NO:	-
BID PACKAGE:	-
DESIGNED BY:	-
CHECKED BY:	-
ISSUE DATE:	2025-10-13
WORKING DATE:	2025-11-13

REVISION
SHEET
T200

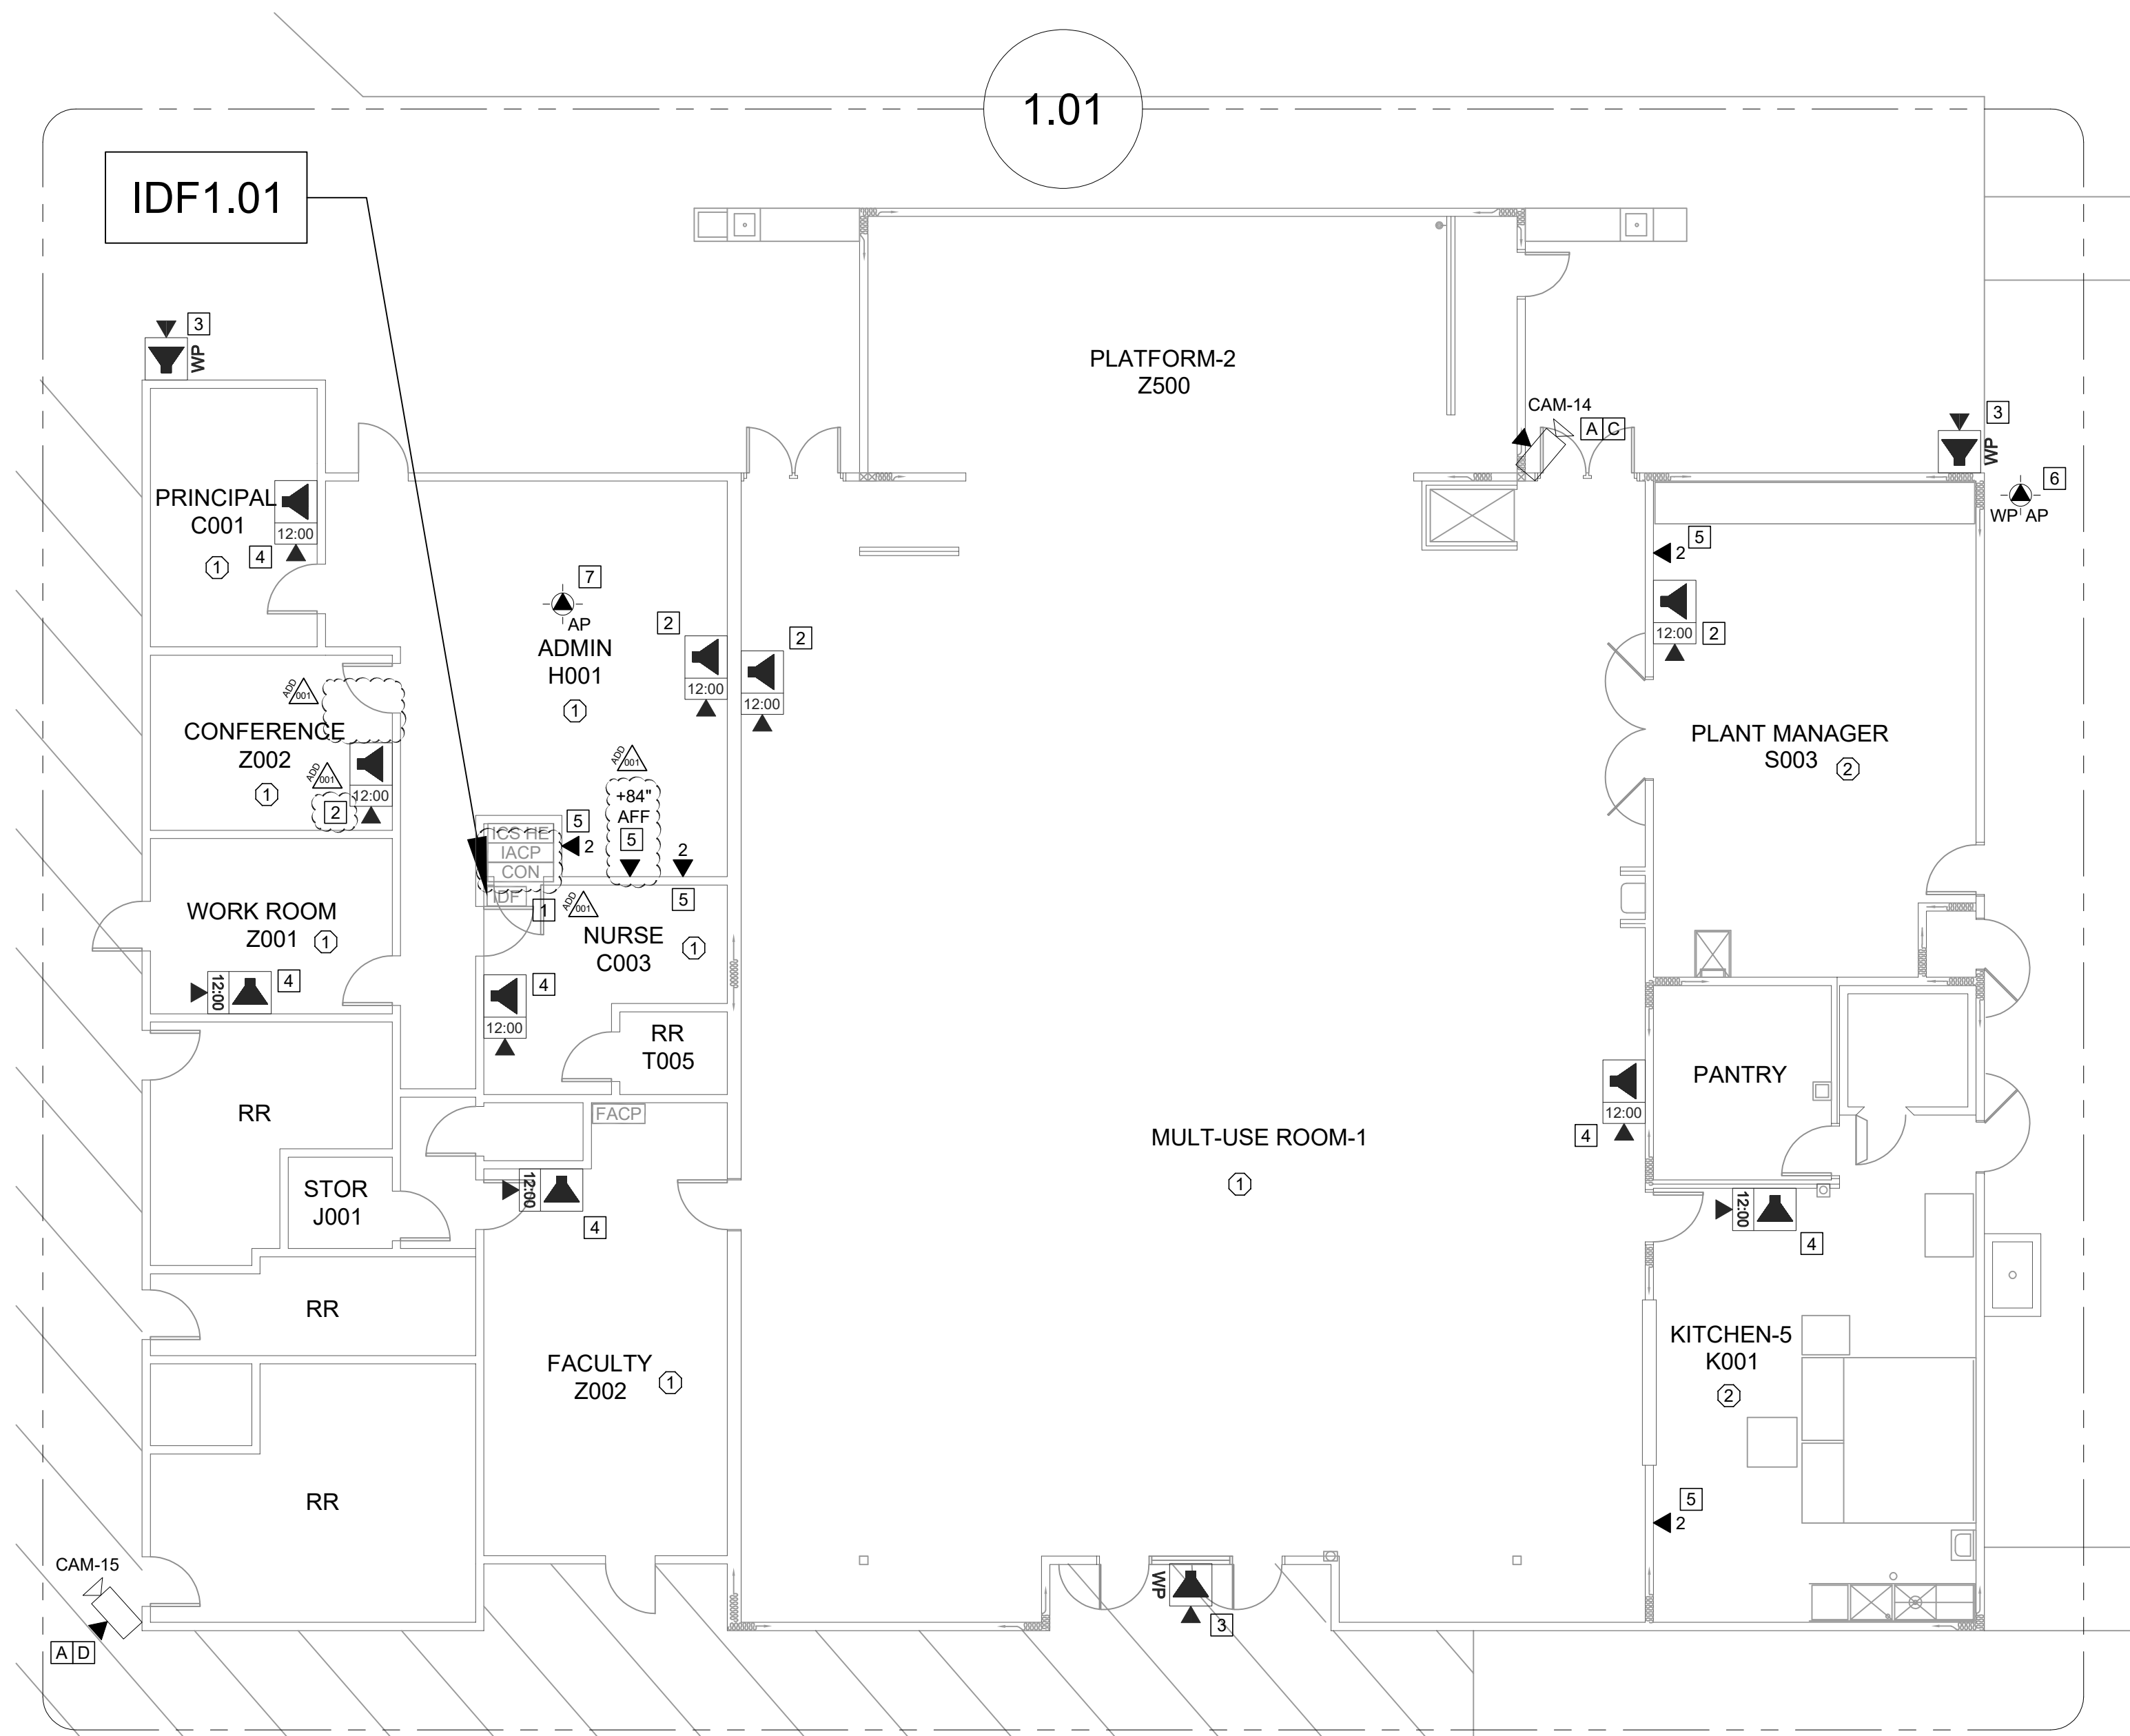

- CEILING CONDITION CHART:

 - ① DROP IN CEILING TILES.
 - ② HARD LID CEILING.
- GENERAL NOTES:

 - NO STRUCTURAL BEAMS SHALL BE PENETRATED OR ALTERED.
 - ALL EQUIPMENT AND MATERIALS ARE CONTRACTOR FURNISHED, INSTALLED, AND CONFIGURED, UNO.
 - CONTRACTOR SHALL TOUCH UP PAINT TO MATCH EXISTING CONDITIONS FOR ALL AREAS OF NEW INSTALL OR DEMOLITION.
- CCTV GENERAL NOTES:

 - ALL (N) EXTERIOR DOME CAMERAS MOUNTED TO WALL SURFACE SHALL HAVE A SUN SHADE INSTALLED.
 - SEE SHEETS T801 AND T900 FOR CAMERA DETAILS.
- SHEET NOTES:


 - PROVIDE (N) EXTERIOR NETWORK SECURITY CAMERA. PROVIDE (N) BACK BOX AS REQUIRED. PROVIDE (N) 1 EA. CAT6A DATA DROP.
 - MOUNT (N) CAMERA ON WALL AT BUILDING CORNER.
 - MOUNT (N) CAMERA UNDER CANOPY AT BUILDING CORNER.
 - MOUNT (N) CAMERA ON BEAM UNDER CANOPY. PROVIDE APPROX. 20' CONDUIT PATHWAY FROM (N) CAMERA DEVICE TO (E) JUNCTION BOX.
 - REWORK MDF/IDF PER RACK ELEVATION. SEE T400/T401.
 - REMOVE (E) CLOCK/SPEAKER AS OCCURS. PROVIDE (N) COMBO BOX WITH (N) SPEAKER, (N) CLASSROOM IP MODULE, AND (N) IP CLOCK. PROVIDE (N) 1 EA. CAT6A DATA DROP. FISH THROUGH WALL TO (N) CUT-IN BOX BEHIND COMBO BACKBOX.
 - PROVIDE (N) EXTERIOR SPEAKER WITH (N) EXTERIOR BACKBOX. PROVIDE (N) INTERIOR ENCLOSURE WITH (N) CLASSROOM IP MODULE. PROVIDE (N) 1 EA. CAT6A DATA DROP AT INTERIOR ENCLOSURE.
 - REMOVE (E) CLOCK/SPEAKER COMBO BAFFLE. PROVIDE (N) RETROFIT BAFFLE WITH (N) SPEAKER, (N) CLASSROOM MODULE, AND (N) IP CLOCK. NOTCH CENTER DIVIDER OF (E) BACKBOX TO ACCOMMODATE CLOCK. PROVIDE (N) 1 EA. CAT6A DATA DROP AND ROUTE INTO (E) BACKBOX VIA (E) CONDUIT STUB TO ACCESSIBLE CEILING.
 - PROVIDE (N) CAT6A DATA DROP. QUANTITY INDICATED. CUT IN AND FISH THROUGH WALL TO ACCESSIBLE CEILING.
 - REWORK (E) DATA DROP AT EXTERIOR AP AND PROVIDE REQUIRED COMPONENTS PER DETAIL 12/T801, 13/T801.
 - INSTALL (N) OWNER-FURNISHED WIRELESS AP AT (E) AP DATA DROP LOCATION. REMOVE (E) WIRELESS AP, AS OCCURS.

TECHNOLOGY FLOOR PLAN NEW - IDF 1.01

SCALE: 1/8"=1'

0 4 8 12 16

KEY PLAN

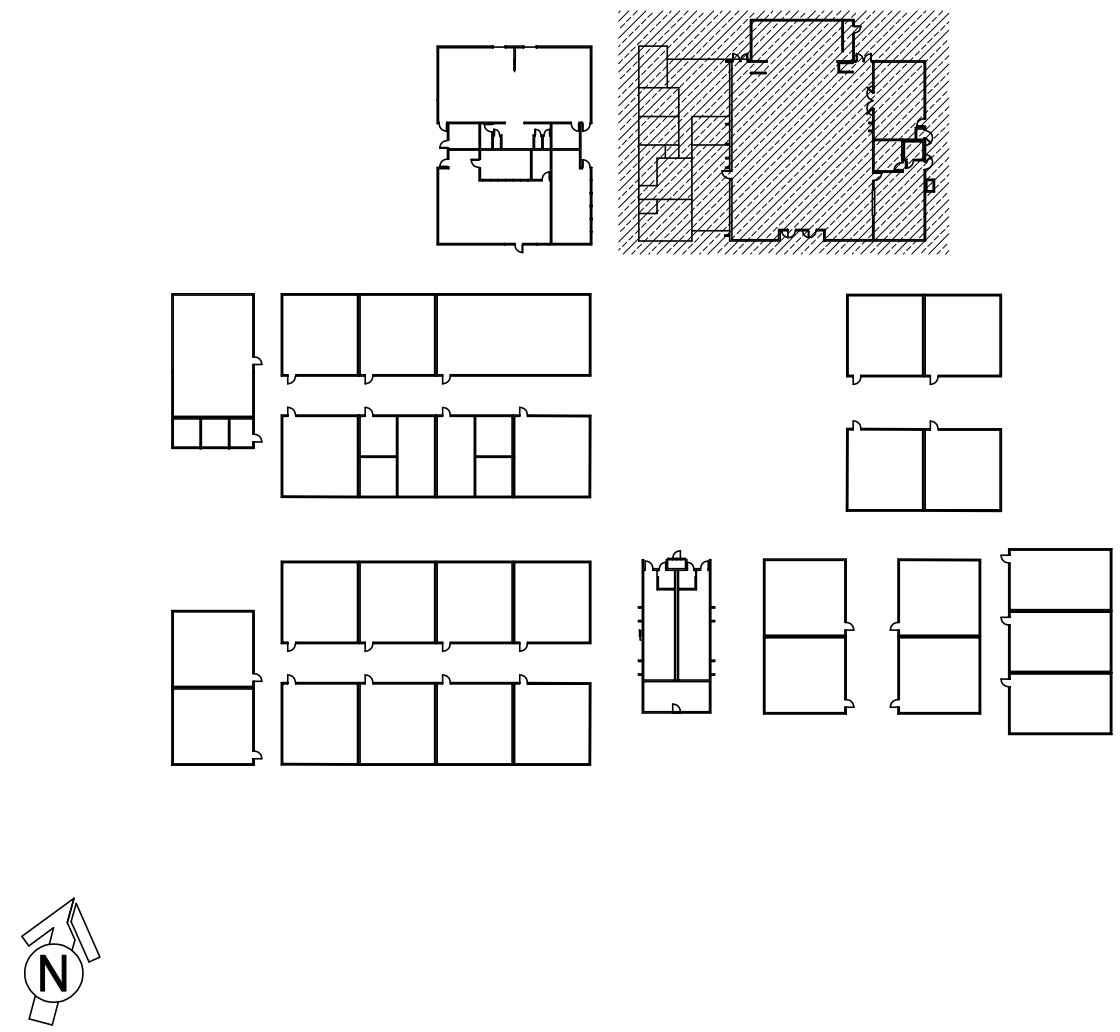

KMM SERVICES, INC

TECHNOLOGY & FIRE LIFE SAFETY

5433 El Camino Ave. Suite 5
Carmichael, CA 95608
Office: (916) 359-4000 www.kmm-services.com

LICENSE STAMPS

REGISTERED COMMUNICATIONS DISTRIBUTION DESIGNER

BICSI

TONY KAGSTRÖM

Signature

EXPIRES 12/31/2027

Reg. No. 163629

Copyright © 2025

These drawings and specifications and the ideas, designs and arrangements represented thereby are and shall remain the property of KMM Services, Inc. and no part thereof shall be copied, disclosed to others, or used in connection with any other work or project other than the specific project for which they have been prepared and developed without the written consent of KMM Services, Inc. Visual contact with these drawings or specifications shall constitute conclusive evidence of these restrictions.

IF DRAWING IS NOT 30"x42" IT IS A REDUCED PRINT

SHEET REVISIONS		
DELTA	DESCRIPTION	DATE
ADD-001		2025-11-13

SITE KEY PLAN

PROJECT

SACRAMENTO CITY

UNIFIED SCHOOL DISTRICT

MARTIN LUTHER KING JR.

TELECENTER UPGRADE

480 LITTLE RIVER WAY

SACRAMENTO, CA 95831

SHEET TITLE

TECHNOLOGY

FLOOR PLAN -

IDF 1.01

DRAWING STATUS


CONSTRUCTION DOCUMENTS

PROJECT NO:	-
BID PACKAGE:	-
DESIGNED BY:	-
CHECKED BY:	-
ISSUE DATE:	2025-10-13
WORKING DATE:	2025-11-13

REVISION



SHEET

T201

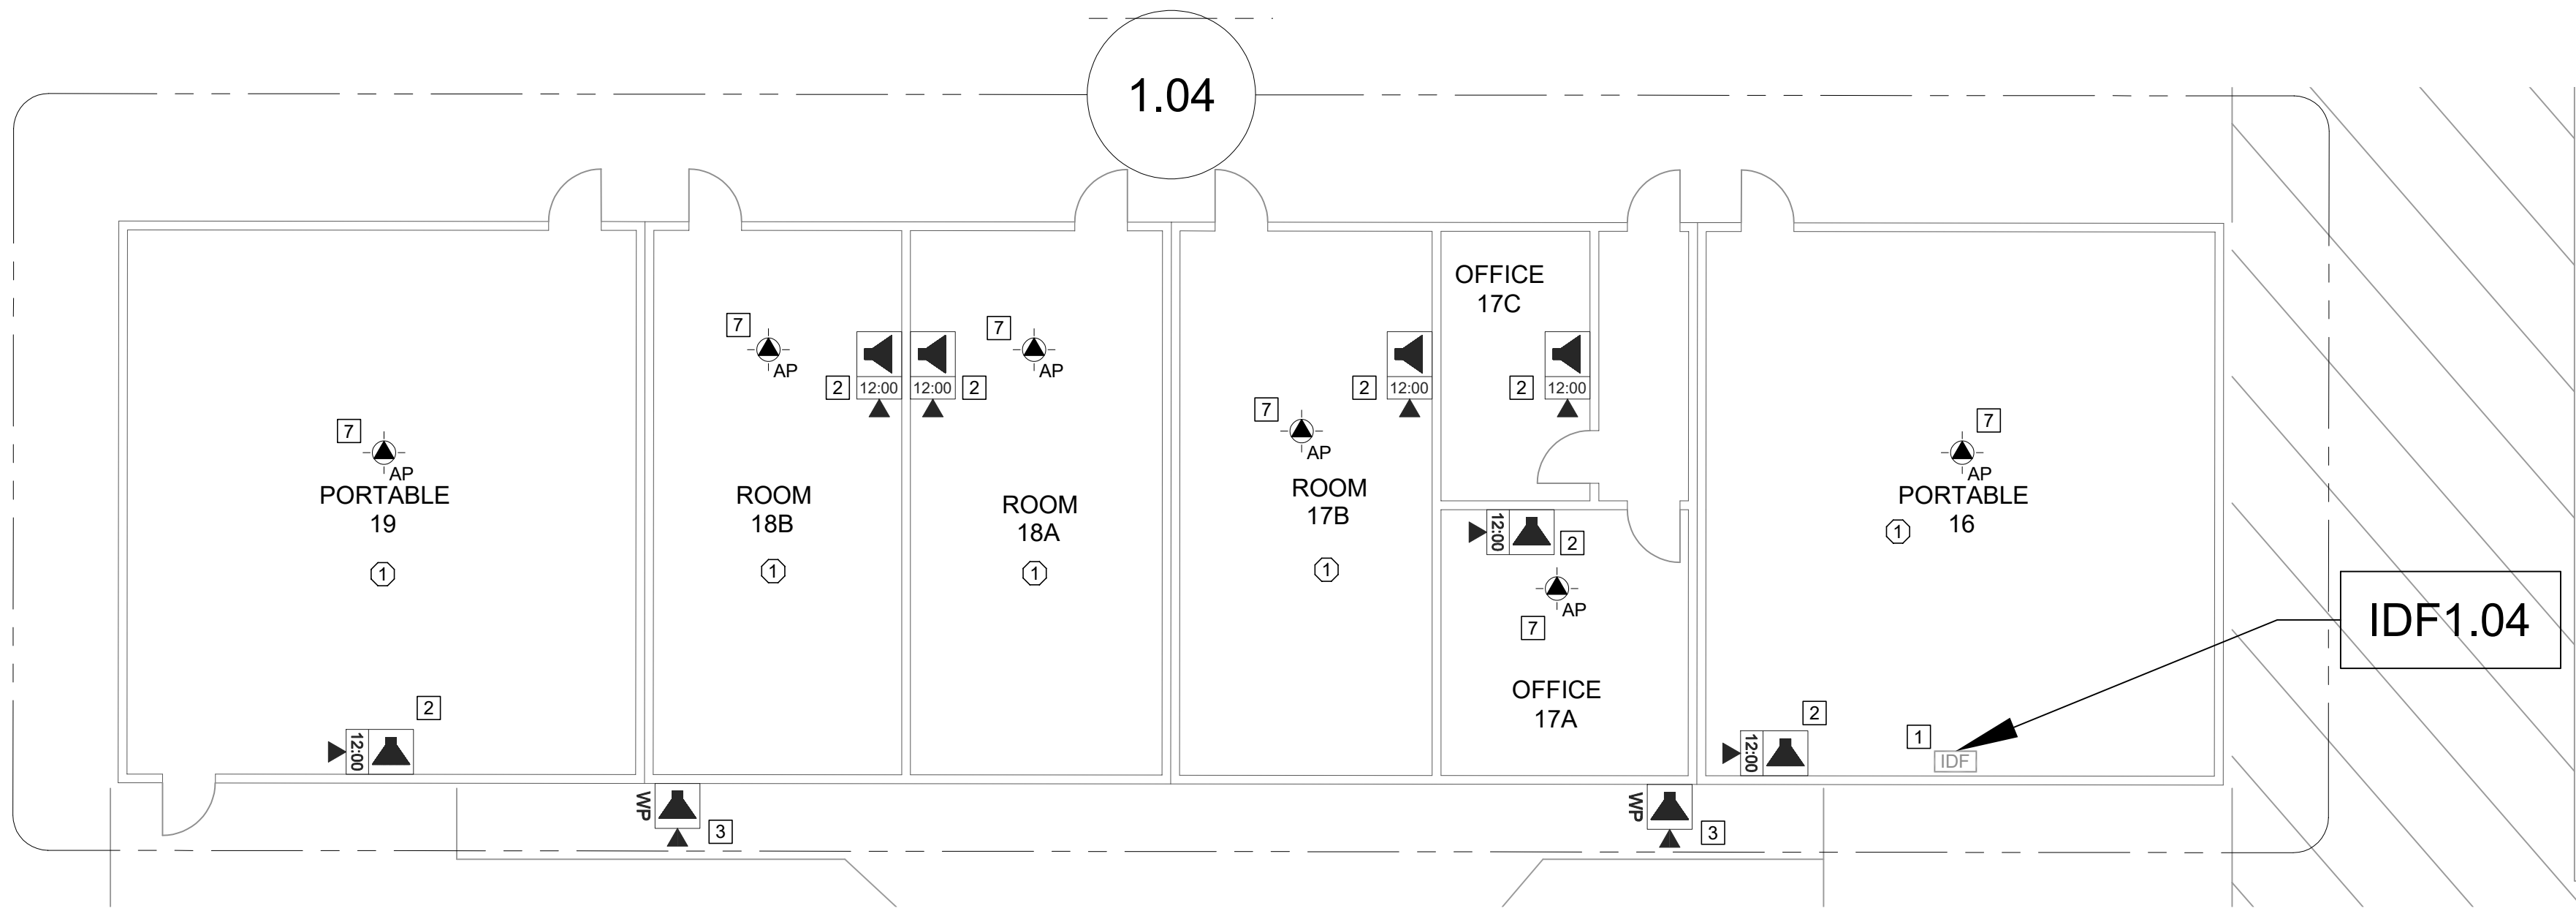


TECHNOLOGY FLOOR PLAN NEW - IDF 1.04

 SCALE: 1/8"=1'

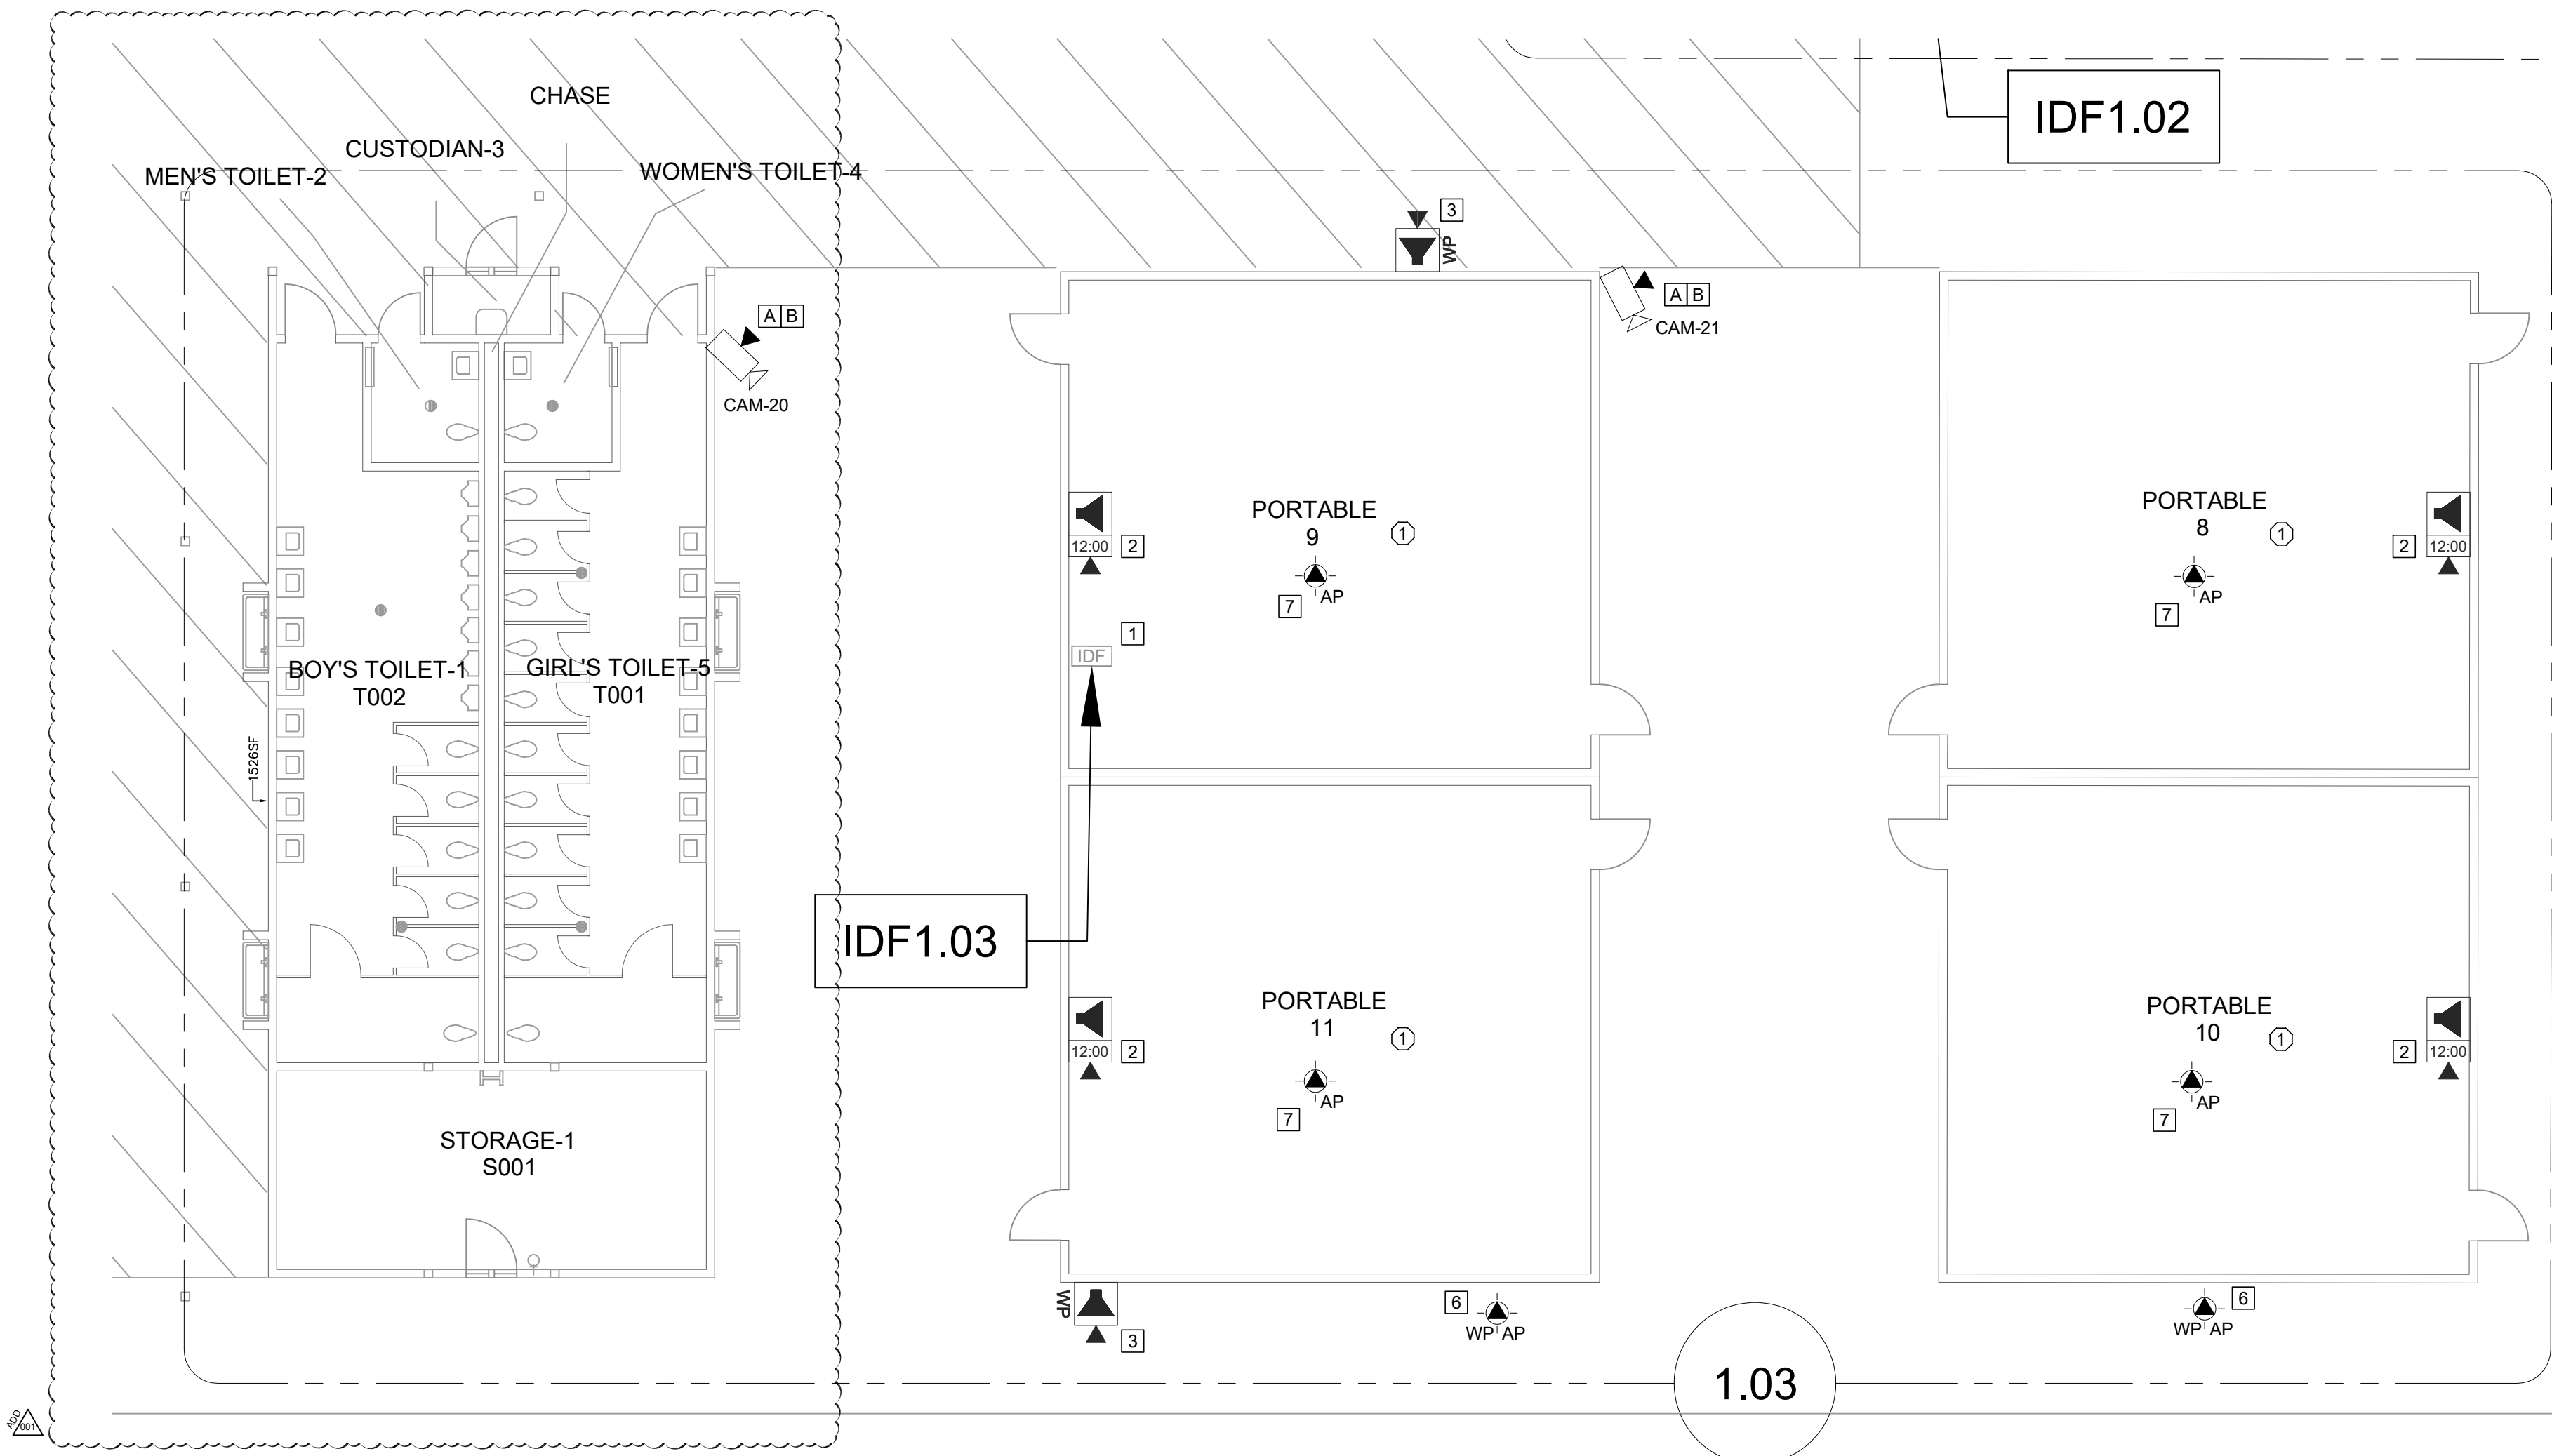

TECHNOLOGY FLOOR PLAN NEW - IDF 1.03

 SCALE: 1/8"=1'



CEILING CONDITION CHART:

- 1 DROP IN CEILING TILES.
- 2 HARD LID CEILING.

GENERAL NOTES:

1. NO STRUCTURAL BEAMS SHALL BE PENETRATED OR ALTERED.
2. ALL EQUIPMENT AND MATERIALS ARE CONTRACTOR FURNISHED, INSTALLED, AND CONFIGURED, UNO.
3. CONTRACTOR SHALL TOUCH UP PAINT TO MATCH EXISTING CONDITIONS FOR ALL AREAS OF NEW INSTALL OR DEMOLITION.

CCTV GENERAL NOTES:

1. ALL (N) EXTERIOR DOME CAMERAS MOUNTED TO WALL SURFACE SHALL HAVE A SUN SHADE INSTALLED.
2. SEE SHEETS T801 AND T900 FOR CAMERA DETAILS.

SHEET NOTES:

- 1 PROVIDE (N) EXTERIOR NETWORK SECURITY CAMERA. PROVIDE (N) BACK BOX AS REQUIRED. PROVIDE (N) 1 EA. CAT6A DATA DROP.
- 2 MOUNT (N) CAMERA ON WALL AT BUILDING CORNER.
- 3 MOUNT (N) CAMERA UNDER CANOPY AT BUILDING CORNER.
- 4 MOUNT (N) CAMERA ON BEAM UNDER CANOPY. PROVIDE APPROX. 20' CONDUIT PATHWAY FROM (N) CAMERA DEVICE TO (E) JUNCTION BOX.
- 1 REWORK MDF/IDF PER RACK ELEVATION. SEE T400/T401.
- 2 REMOVE (E) CLOCK/SPEAKER AS OCCURS. PROVIDE (N) COMBO BOX WITH (N) SPEAKER, (N) CLASSROOM IP MODULE, AND (N) IP CLOCK. PROVIDE (N) 1 EA. CAT6A DATA DROP. FISH THROUGH WALL TO (N) CUT-IN BOX BEHIND COMBO BACKBOX.
- 3 PROVIDE (N) EXTERIOR SPEAKER WITH (N) EXTERIOR BACKBOX. PROVIDE (N) INTERIOR ENCLOSURE WITH (N) CLASSROOM IP MODULE. PROVIDE (N) 1 EA. CAT6A DATA DROP AT INTERIOR ENCLOSURE.
- 4 REMOVE (E) CLOCK/SPEAKER COMBO BAFFLE. PROVIDE (N) RETROFIT BAFFLE WITH (N) SPEAKER, (N) CLASSROOM MODULE, AND (N) IP CLOCK. NOTCH CENTER DIVIDER OF (E) BACKBOX TO ACCOMMODATE CLOCK. PROVIDE (N) 1 EA. CAT6A DATA DROP AND ROUTE INTO (E) BACKBOX VIA (E) CONDUIT STUB TO ACCESSIBLE CEILING.
- 5 PROVIDE (N) CAT6A DATA DROP. QUANTITY INDICATED. CUT IN AND FISH THROUGH WALL TO ACCESSIBLE CEILING.
- 6 REWORK (E) DATA DROP AT EXTERIOR AP AND PROVIDE REQUIRED COMPONENTS PER DETAIL 12/T801, 13/T801.
- 7 INSTALL (N) OWNER-FURNISHED WIRELESS AP AT (E) AP DATA DROP LOCATION. REMOVE (E) WIRELESS AP, AS OCCURS.



KMM SERVICES, INC
TECHNOLOGY & FIRE LIFE SAFETY

5433 El Camino Ave. Suite 5
Carmichael, CA 95608
Office: (916) 359-4000 www.kmm-services.com

LICENSE STAMPS



Copyright © 2025

These drawings and specifications and the ideas, designs and arrangements represented thereby are and shall remain the property of KMM Services, Inc. and no part thereof shall be copied, disclosed to others, or used in connection with any other work or project other than the specific project for which they have been prepared and developed without the written consent of KMM Services, Inc. Visual contact with these drawings or specifications shall constitute conclusive evidence of these restrictions.

IF DRAWING IS NOT 30"x42" IT IS A REDUCED PRINT

SHEET REVISIONS

DELTA	DESCRIPTION	DATE
ADD-001		2025-11-13

SITE KEY PLAN

PROJECT
SACRAMENTO CITY
UNIFIED SCHOOL DISTRICT
MARTIN LUTHER KING JR.
TELECENTER UPGRADE
480 LITTLE RIVER WAY
SACRAMENTO, CA 95831

SHEET TITLE

TECHNOLOGY
FLOOR PLAN -
IDF 1.03 AND 1.04

DRAWING STATUS

CONSTRUCTION DOCUMENTS


PROJECT NO:	-
BID PACKAGE:	-
DESIGNED BY:	-
CHECKED BY:	-
ISSUE DATE:	2025-10-13
WORKING DATE:	2025-11-13


REVISION

SHEET

T203

KEY PLAN

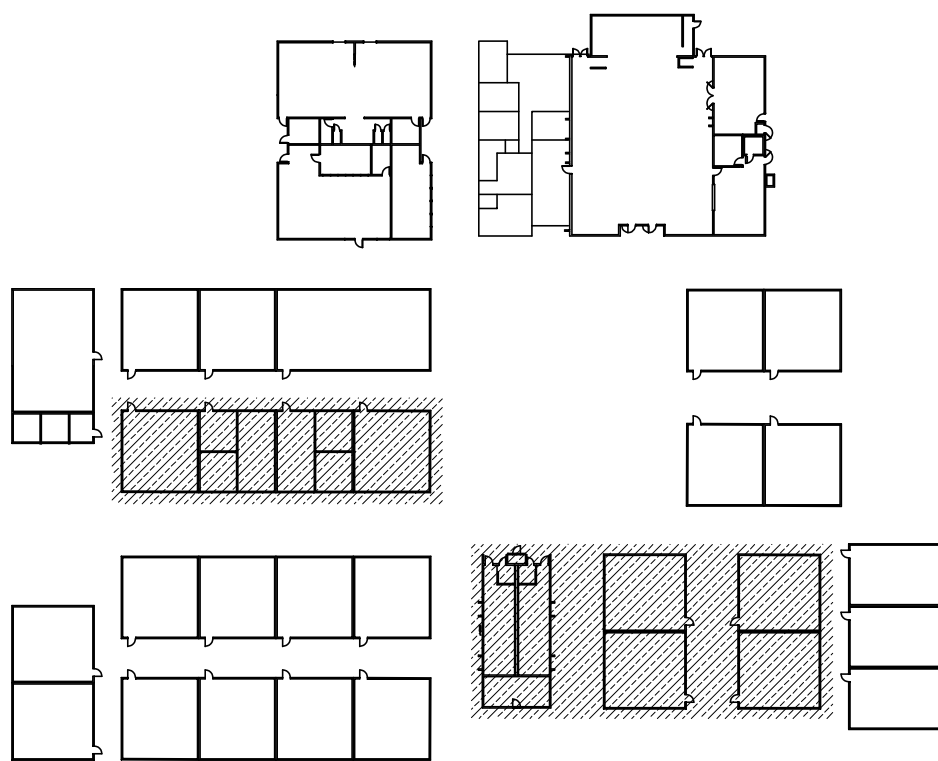

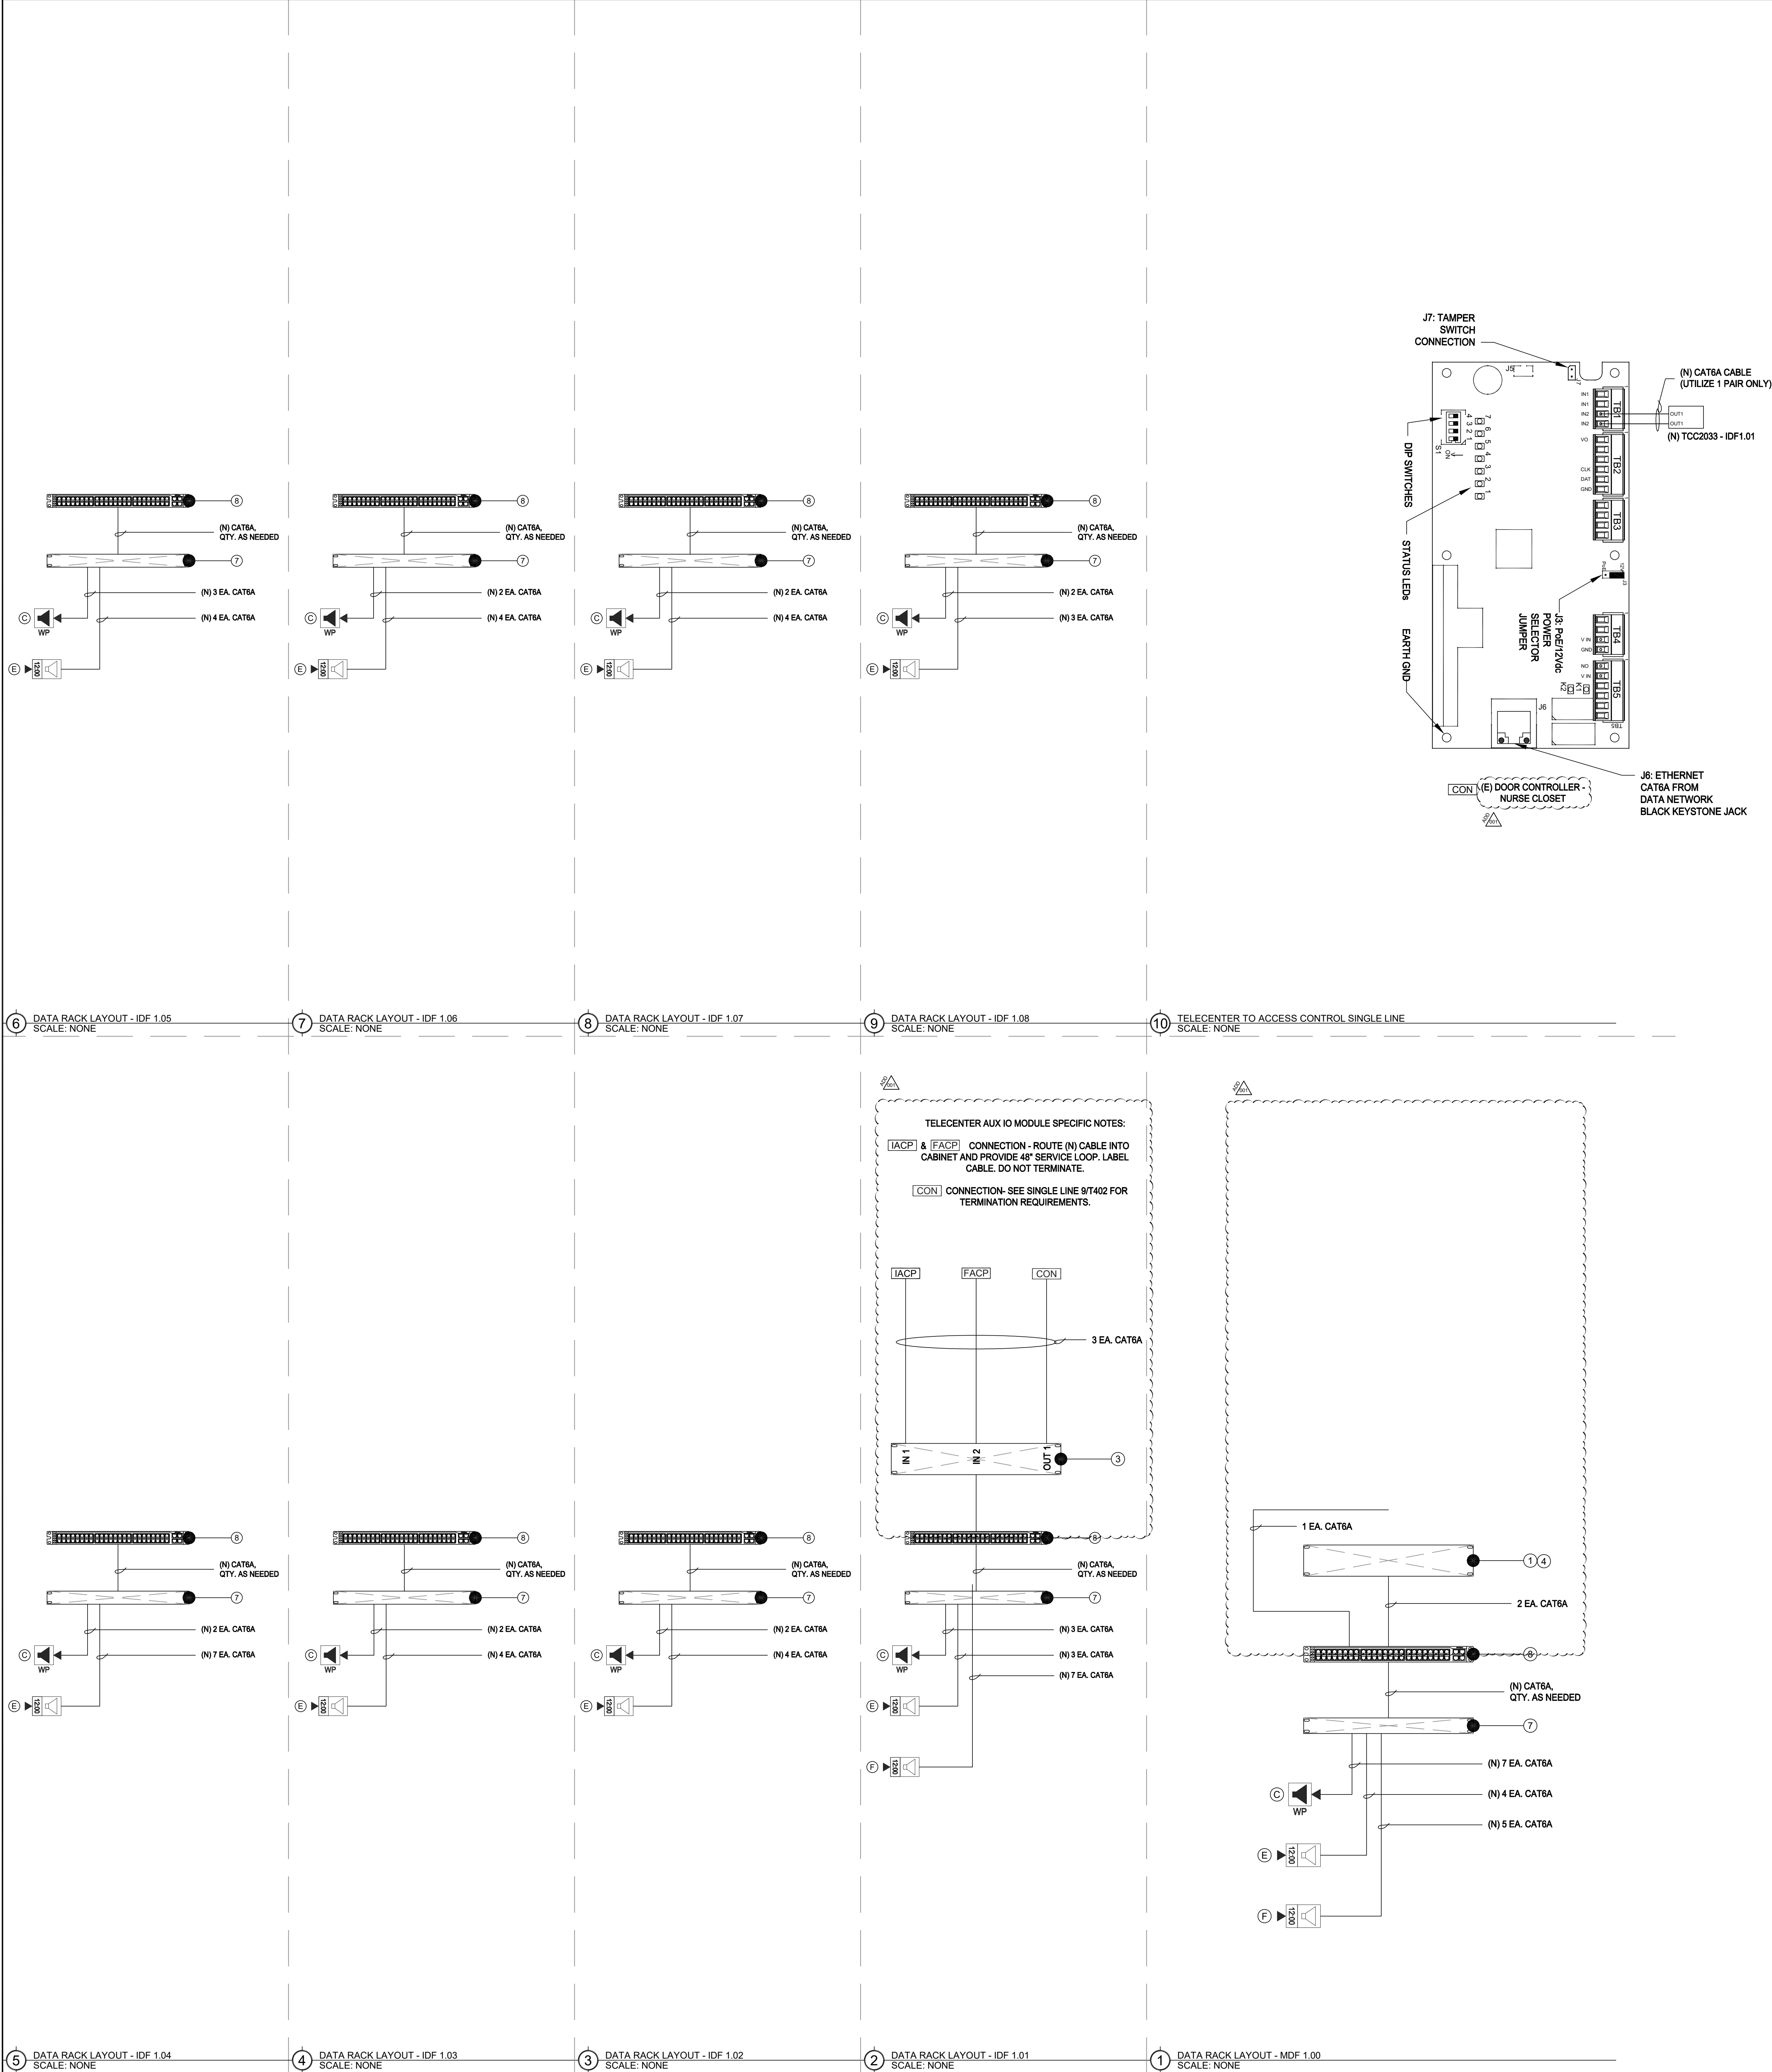

EQUIPMENT INTERCOM SCHEDULE: ALL EQUIPMENT AND MATERIALS ARE CONTRACTOR FURNISHED, INSTALLED AND CONFIGURED (UNO)				
SYMBOL	DESCRIPTION	MODEL	PART NUMBER	NOTES / DETAIL REFERENCES
①	TELECENTER U IP CONTROLLER	RAULAND	TCC2000	N/A
②	TELECENTER U ADMIN CONSOLE		TCC2045	N/A [TCL-CON]
③	TELECENTER U AUX. IN/OUT. MODULE		TCC2033	N/A
	UNIVERSAL RACK MOUNTING KIT		TCC2099	N/A
④	TELECENTER U PROGRAM LINE INPUT MODULE		TCC2065	N/A
⑦	24-PORT OR 48-PORT PATCH PANEL	SEE DATA TECHNOLOGY RACK ELEVATIONS BELOW FOR MORE INFORMATION.		(N) OR (E) AS NOTED
⑧	48-PORT NETWORK SWITCH	SEE DATA TECHNOLOGY RACK ELEVATIONS BELOW FOR MORE INFORMATION.		(N) OR (E) AS NOTED
[IACP]	INTRUSION ALARM CONTROL PANEL	EXISTING	EXISTING	N/A
[FACP]	FIRE ALARM CONTROL PANEL	EXISTING	EXISTING	N/A
[CON]	ACCESS CONTROL PANEL	EXISTING	EXISTING	N/A

EQUIPMENT SCHEDULE INTERIOR SURFACE SPEAKER: ALL EQUIPMENT AND MATERIALS ARE CONTRACTOR FURNISHED, INSTALLED AND CONFIGURED (UNO)				
DESCRIPTION	MODEL	PART NUMBER	NOTES / DETAIL REFERENCES	
TELECENTER U IP CLASSROOM MODULE	RAULAND	TCC2011B	MOUNT INSIDE ENCLOSURE	
8 OHM, 8" SPEAKER WITH RJ45 CONNECTOR	RAULAND	US0880	N/A	
SPEAKER BAFFLE	RAULAND	ACC1003	N/A	
SURFACE MOUNT SPEAKER ENCLOSURE	RAULAND	ACC1112	N/A	

EQUIPMENT SCHEDULE EXTERIOR SURFACE SPEAKER: ALL EQUIPMENT AND MATERIALS ARE CONTRACTOR FURNISHED, INSTALLED AND CONFIGURED (UNO)				
DESCRIPTION	MODEL	PART NUMBER	NOTES / DETAIL REFERENCES	
TELECENTER U IP CLASSROOM MODULE	RAULAND	TCC2011B	MOUNT INSIDE BUILDING	
TELECENTER U BREAKOUT MODULE	RAULAND	603101	MOUNT INSIDE BUILDING	
8 OHM, 8" MOISTURE RESISTANT SPEAKER	LOWELL	8C10MRB	N/A	
GRILLE VANDAL RESISTANT	RAULAND	ACC1012	N/A	
SURFACE MOUNT SPEAKER ENCLOSURE	RAULAND	ACC1113	N/A	
(N) SURFACE MOUNTED 4 GANG BACKBOX - WHITE	FSR	SMWB-4G-WHT	MOUNT INSIDE BUILDING	

EQUIPMENT SCHEDULE LARGE MESSAGE BOARD: ALL EQUIPMENT AND MATERIALS ARE CONTRACTOR FURNISHED, INSTALLED AND CONFIGURED (UNO)				
DESCRIPTION	MODEL	PART NUMBER	NOTES / DETAIL REFERENCES	
LARGE MESSAGE BOARD	RAULAND	TCC3012L	N/A	
PROTECTIVE CAGE	AMERICAN TIME	G20550F-28	N/A	

EQUIPMENT SCHEDULE INTERIOR SURFACE CLOCK/SPEAKER COMBO: ALL EQUIPMENT AND MATERIALS ARE CONTRACTOR FURNISHED, INSTALLED AND CONFIGURED (UNO)				
DESCRIPTION	MODEL	PART NUMBER	NOTES / DETAIL REFERENCES	
TELECENTER U IP CLASSROOM MODULE	RAULAND	TCC2011B	MOUNT IN ENCLOSURE	
IP DIGITAL CLOCK	RAULAND	TCC3011S	N/A	
BAFFLE ASSEMBLY WITH SPEAKER	RAULAND	ACC3011S	N/A	
SURFACE MOUNT ENCLOSURE CLOCK/SPEAKER COMBO	RAULAND	ACC3011SBB	N/A	

EQUIPMENT SCHEDULE INTERIOR RETROFIT CLOCK/SPEAKER COMBO: ALL EQUIPMENT AND MATERIALS ARE CONTRACTOR FURNISHED, INSTALLED AND CONFIGURED (UNO)				
DESCRIPTION	MODEL	PART NUMBER	NOTES / DETAIL REFERENCES	
TELECENTER U IP CLASSROOM MODULE	RAULAND	TCC2011B	MOUNT IN ENCLOSURE	
IP DIGITAL CLOCK	RAULAND	TCC3011S	N/A	
8 OHM 8" SPEAKER WITH RJ45 CONNECTOR	RAULAND	US0880	N/A	
RETROFIT BAFFLE	LOWELL	C100-5526	NOTCH CENTER DIVIDER OF (E) FLUSH BACKBOX	

ACTION MATRIX: INTERCONNECTIONS TO OTHER SYSTEMS				
TCC2033 (IDF 1.01)				
MODULES	IN-1	IN-2	OUT-1	OUT-2
I/O PORTS			[C]	
EVENT: LOCKDOWN				
EVENT: INTRUSION ALARM ACTIVE	[A]			
EVENT: FIRE ALARM ACTIVE		[B]		
[A]	INPUT: CLOSURE FROM INTRUSION ALARM PANEL			
[B]	INPUT: CLOSURE FROM FIRE ALARM PANEL			
[C]	OUTPUT: CLOSURE TO ACCESS CONTROL			



KMM SERVICES, INC
TECHNOLOGY & FIRE LIFE SAFETY

5433 El Camino Ave. Suite 5
Carmichael, CA 95608
Office: (916) 359-4000 www.kmm-services.com



Copyright © 2025
These drawings and specifications and the ideas, designs and arrangements represented thereby are and shall remain the property of KMM Services, Inc. and no part thereof shall be copied, disclosed to others, or used in connection with any other work or project other than the specific project for which they have been prepared and developed without the written consent of KMM Services, Inc. Visual contact with these drawings or specifications shall constitute conclusive evidence of these restrictions.

IF DRAWING IS NOT 30"x42" IT IS A REDUCED PRINT

SHEET REVISIONS		
DELTA	DESCRIPTION	DATE
ADD-001		2025-11-13

SITE KEY PLAN

PROJECT
SACRAMENTO CITY
UNIFIED SCHOOL DISTRICT
MARTIN LUTHER KING JR.
TELECENTER UPGRADE
480 LITTLE RIVER WAY
SACRAMENTO, CA 95831

SHEET TITLE
TECHNOLOGY
SINGLE LINE DIAGRAMS

DRAWING STATUS
CONSTRUCTION DOCUMENTS

PROJECT NO:	-
BID PACKAGE:	-
DESIGNED BY:	-
CHECKED BY:	-
ISSUE DATE:	2025-10-13
WORKING DATE:	2025-11-13

REVISION

SHEET
T403