


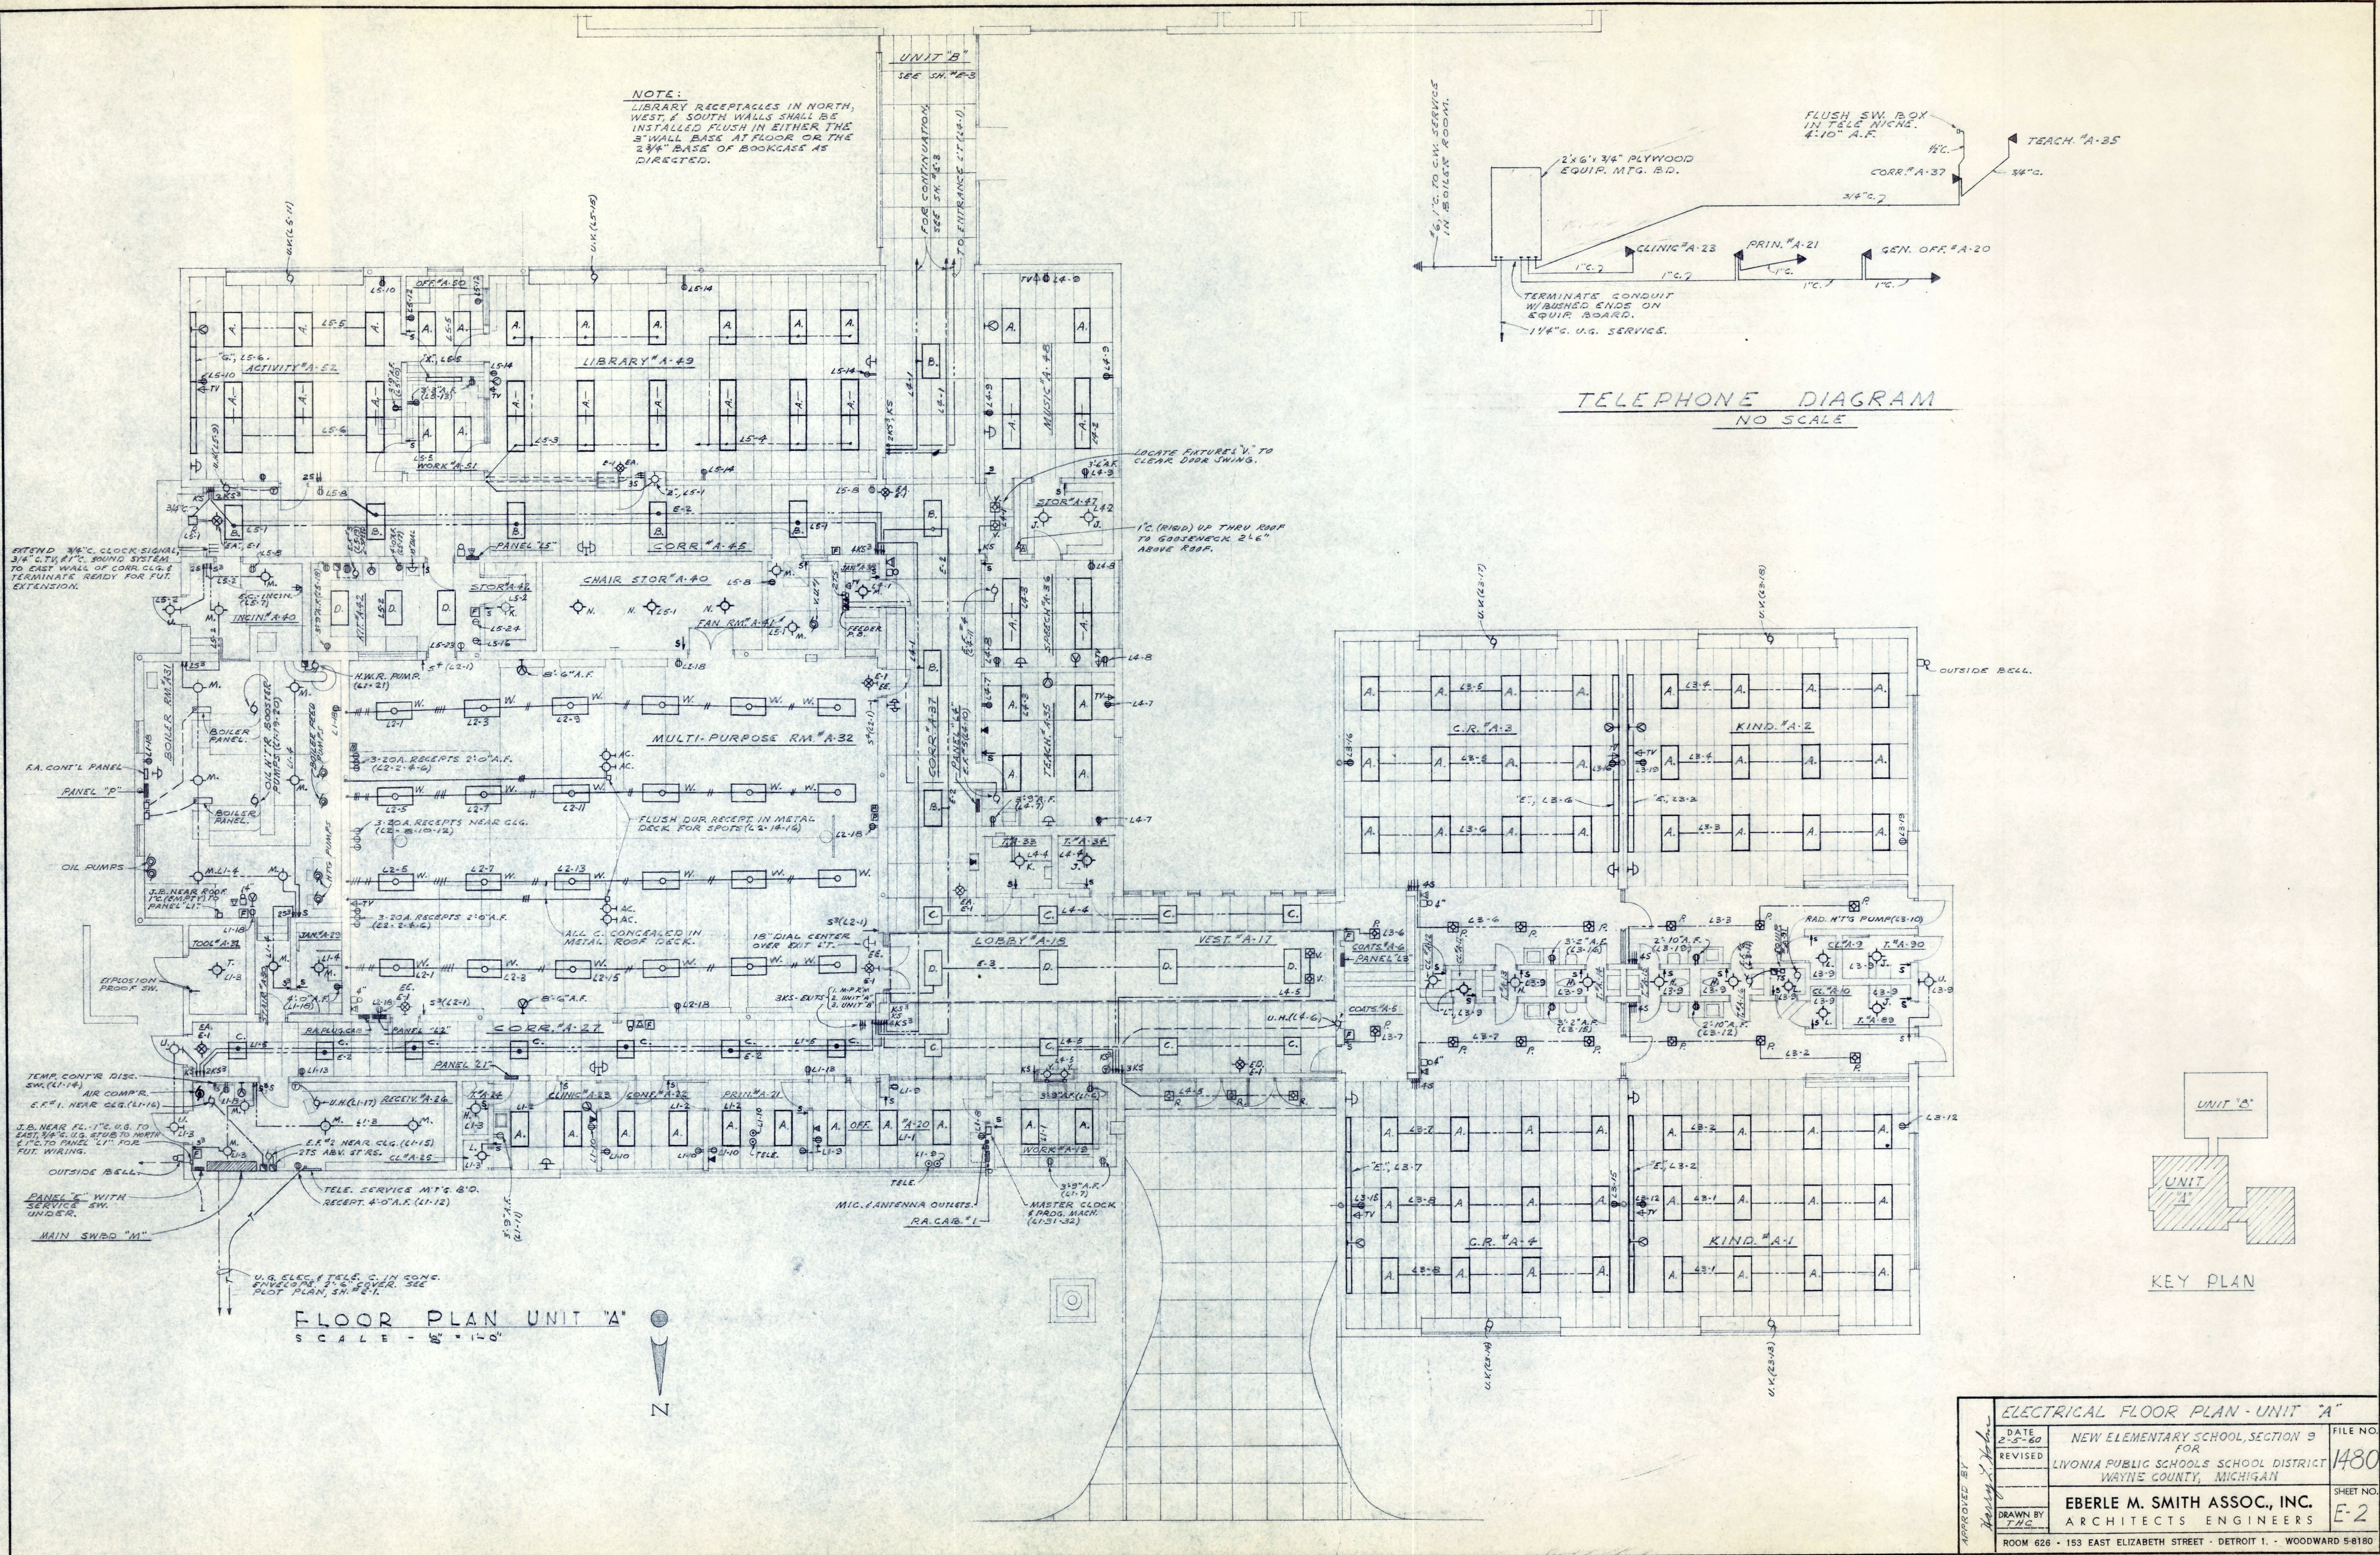
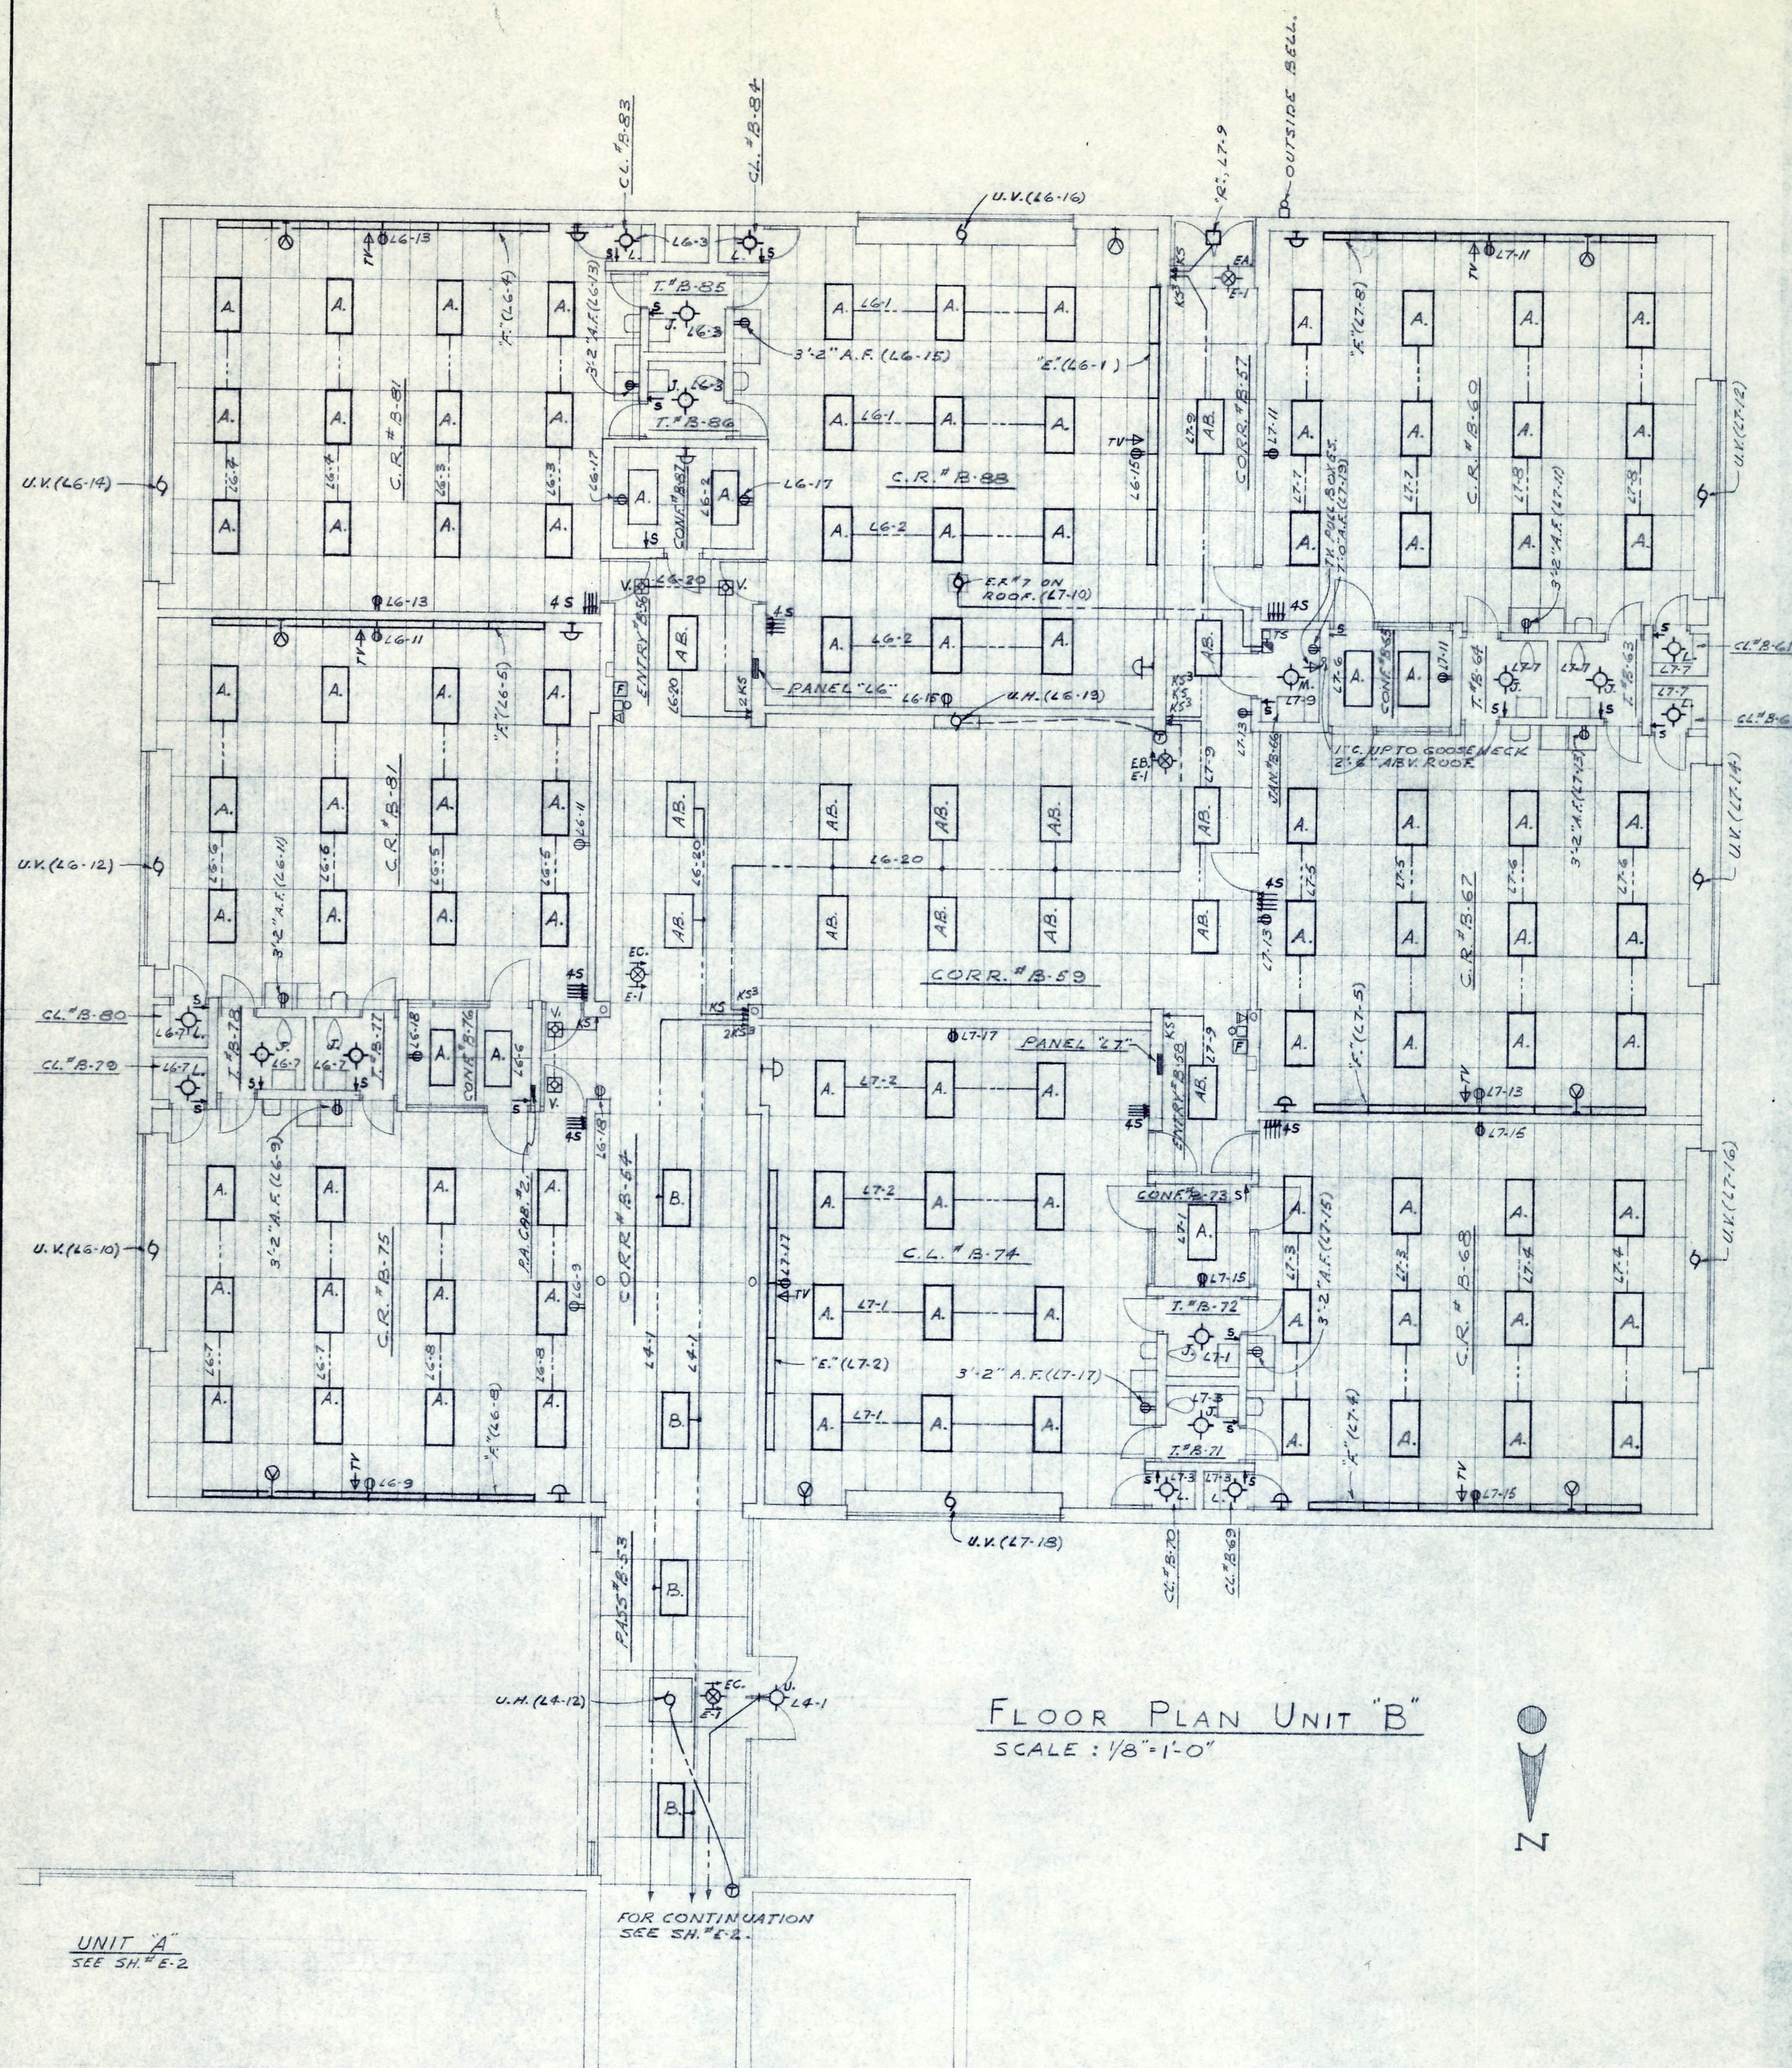


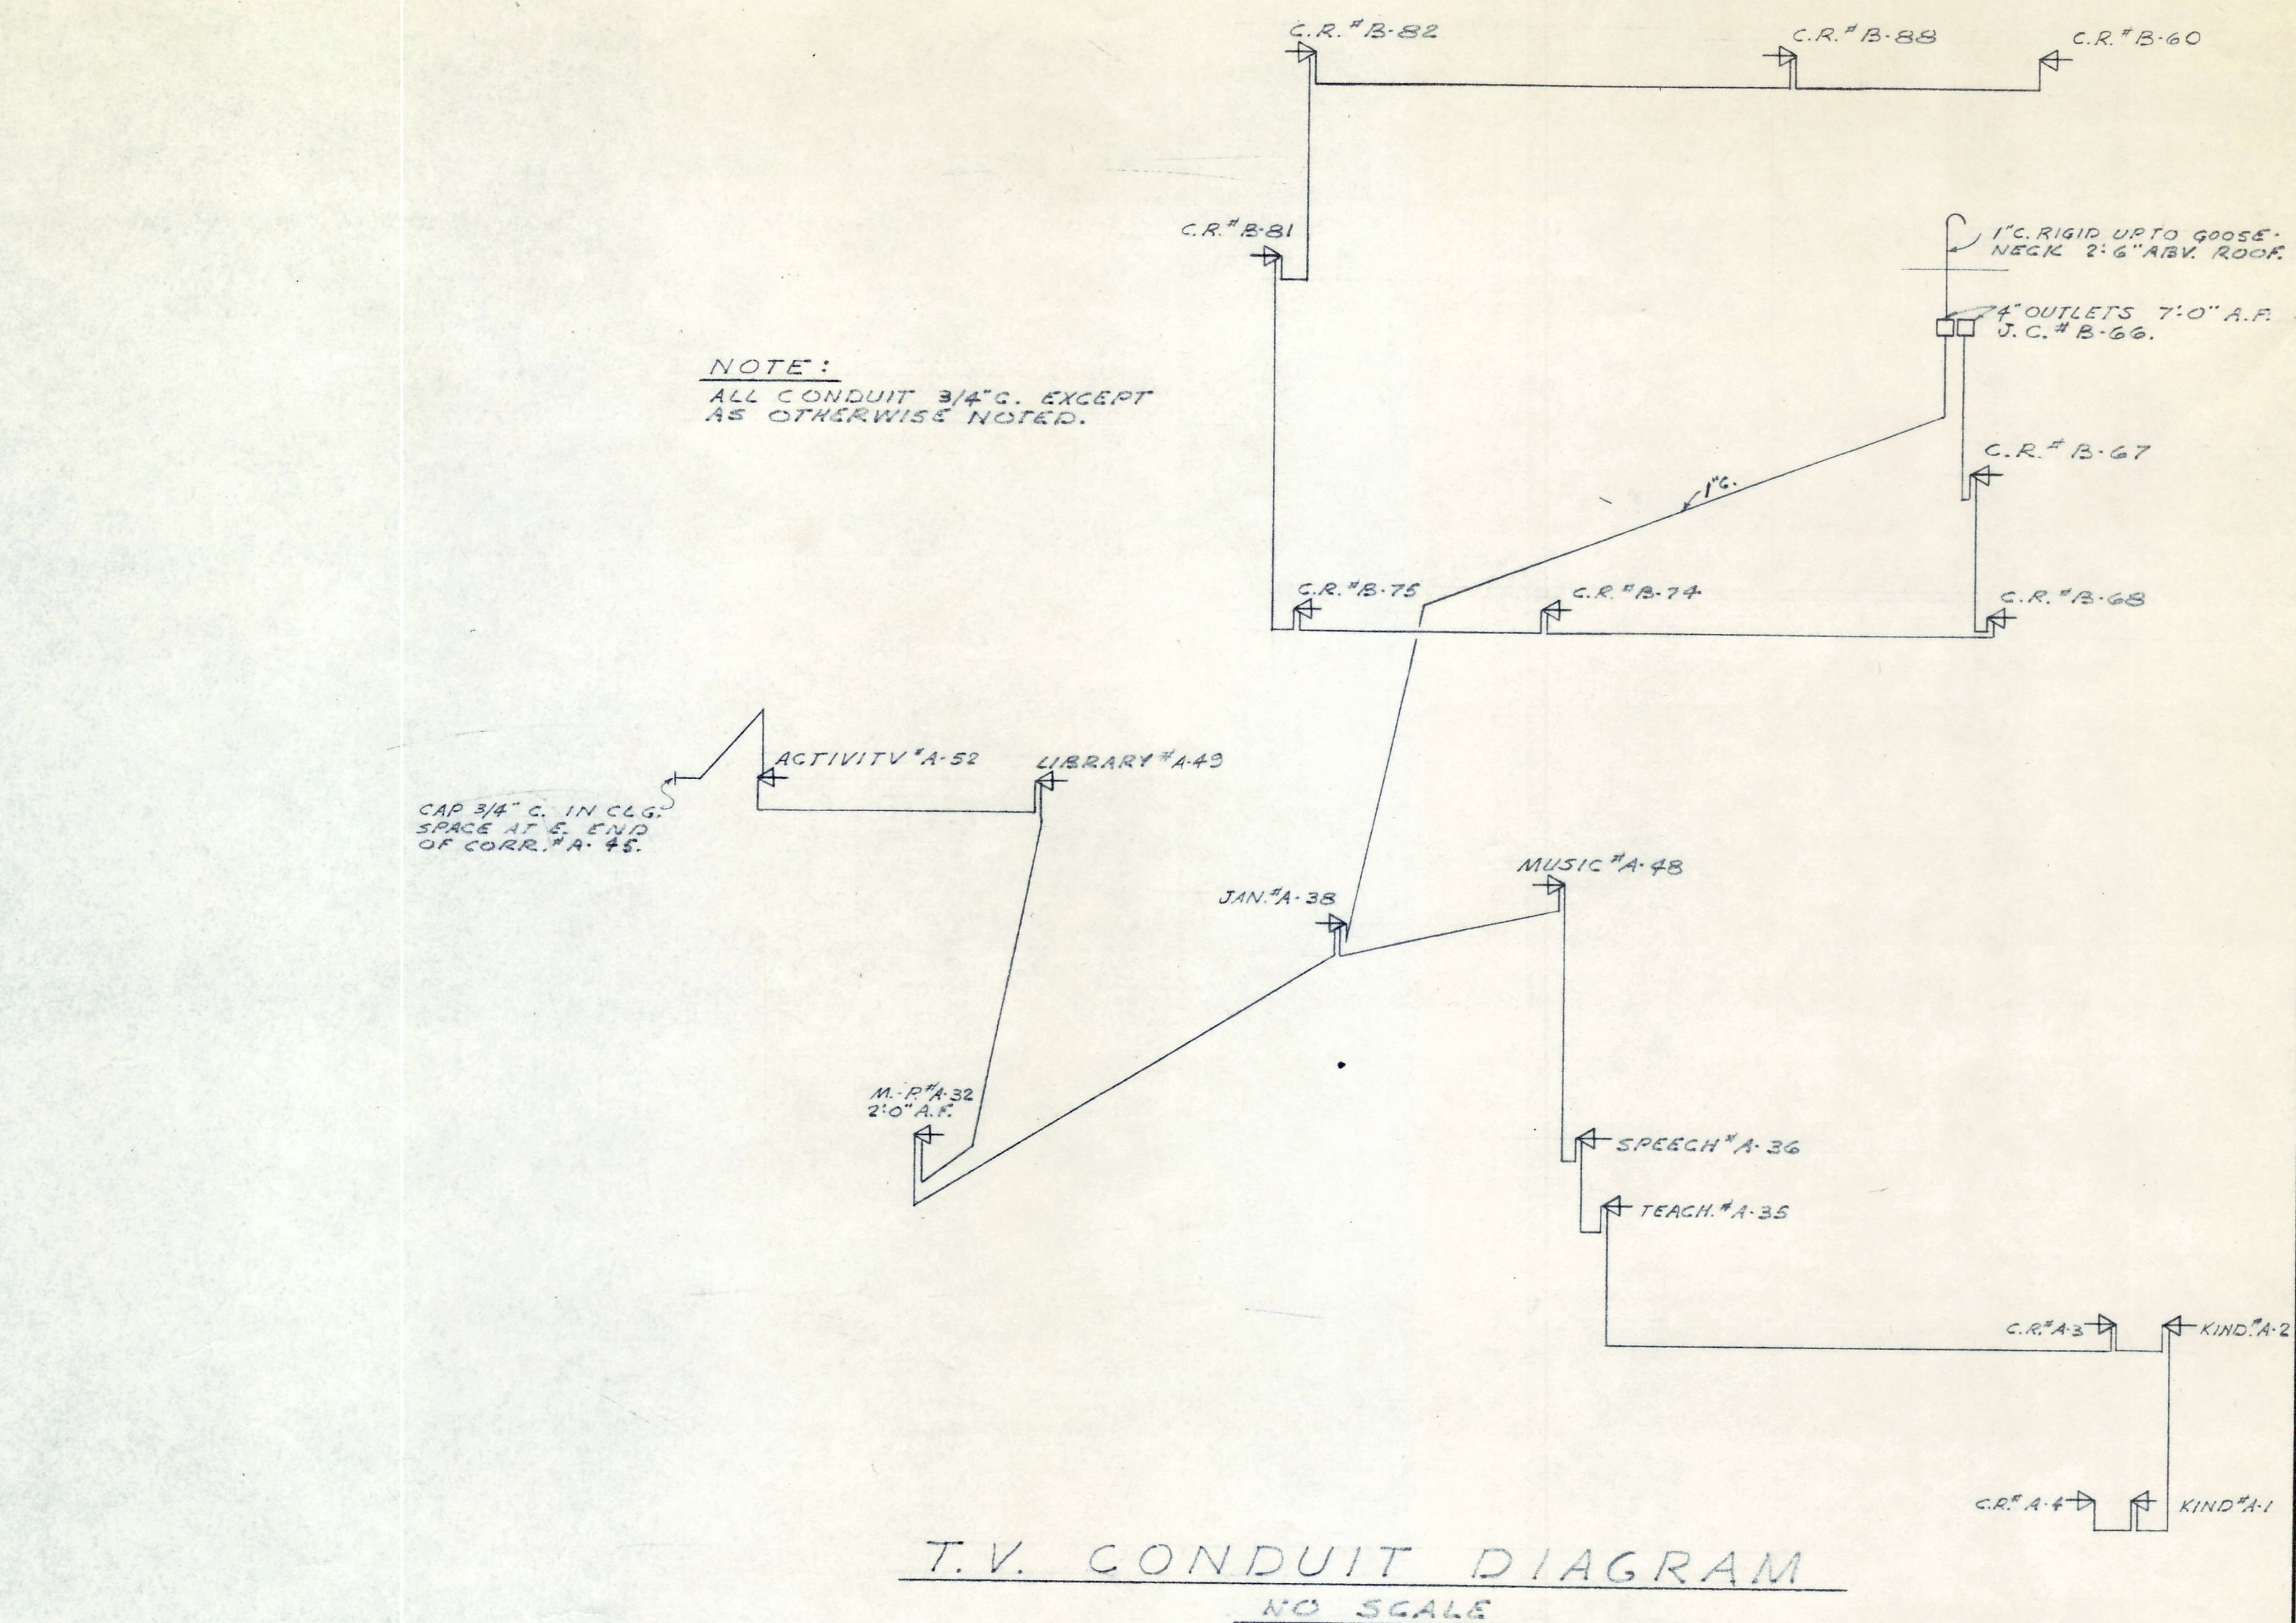


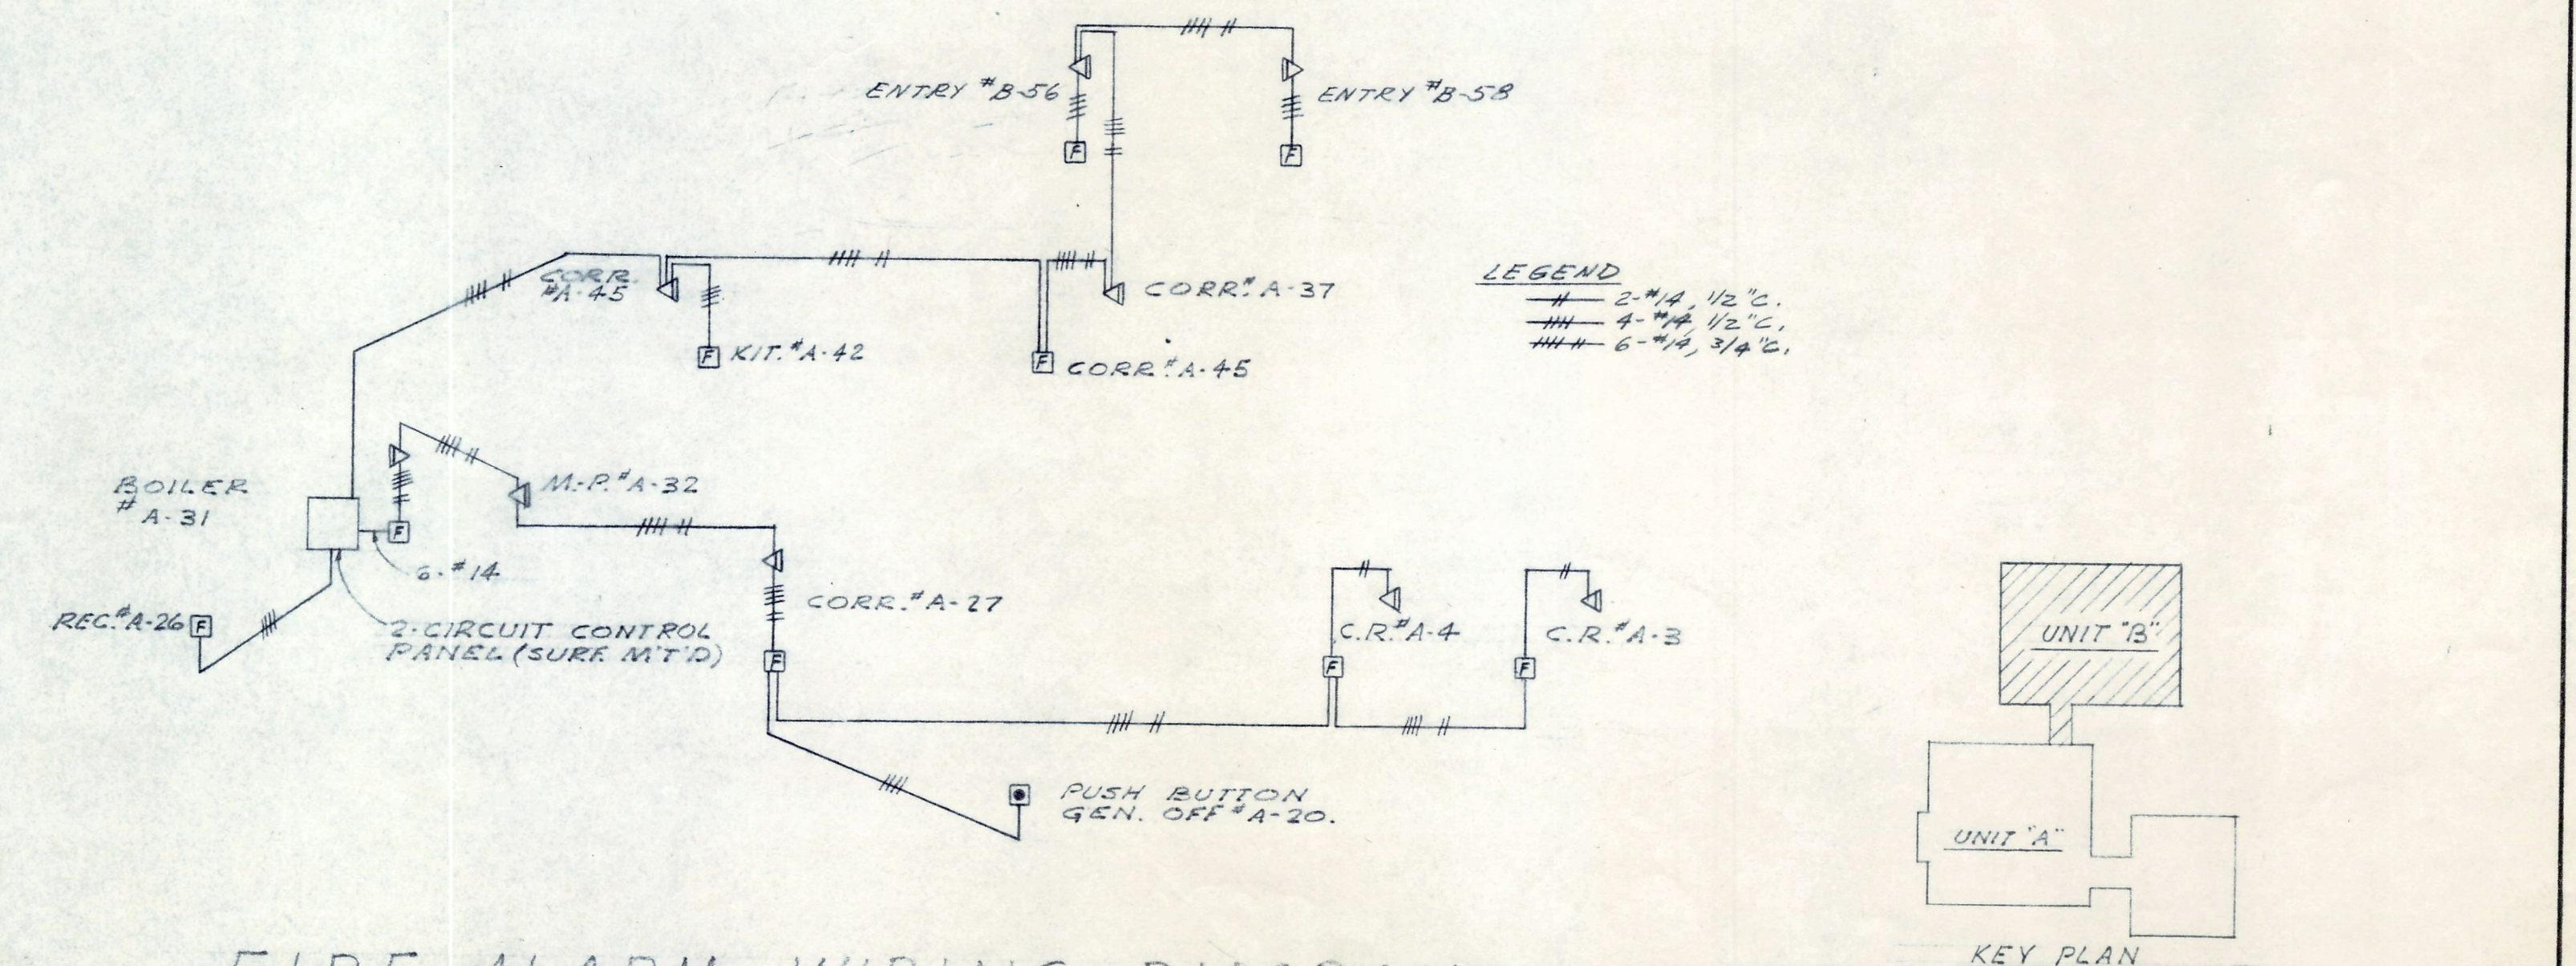

ELECTRICAL FLOOR PLAN UNIT "B"			
DATE	NEW ELEMENTARY SCHOOL, SECTION 9	FILE NO.	
REVISION	LIVONIA PUBLIC SCHOOLS SCHOOL DISTRICT	1480	
	WAYNE COUNTY, MICHIGAN		
DRAWN BY	EBERLE M. SMITH ASSOC., INC.	SHEET NO.	E-3
	ARCHITECTS ENGINEERS		
ROOM 626 • 153 EAST ELIZABETH STREET • DETROIT 1 • WOODWARD 5-8180			

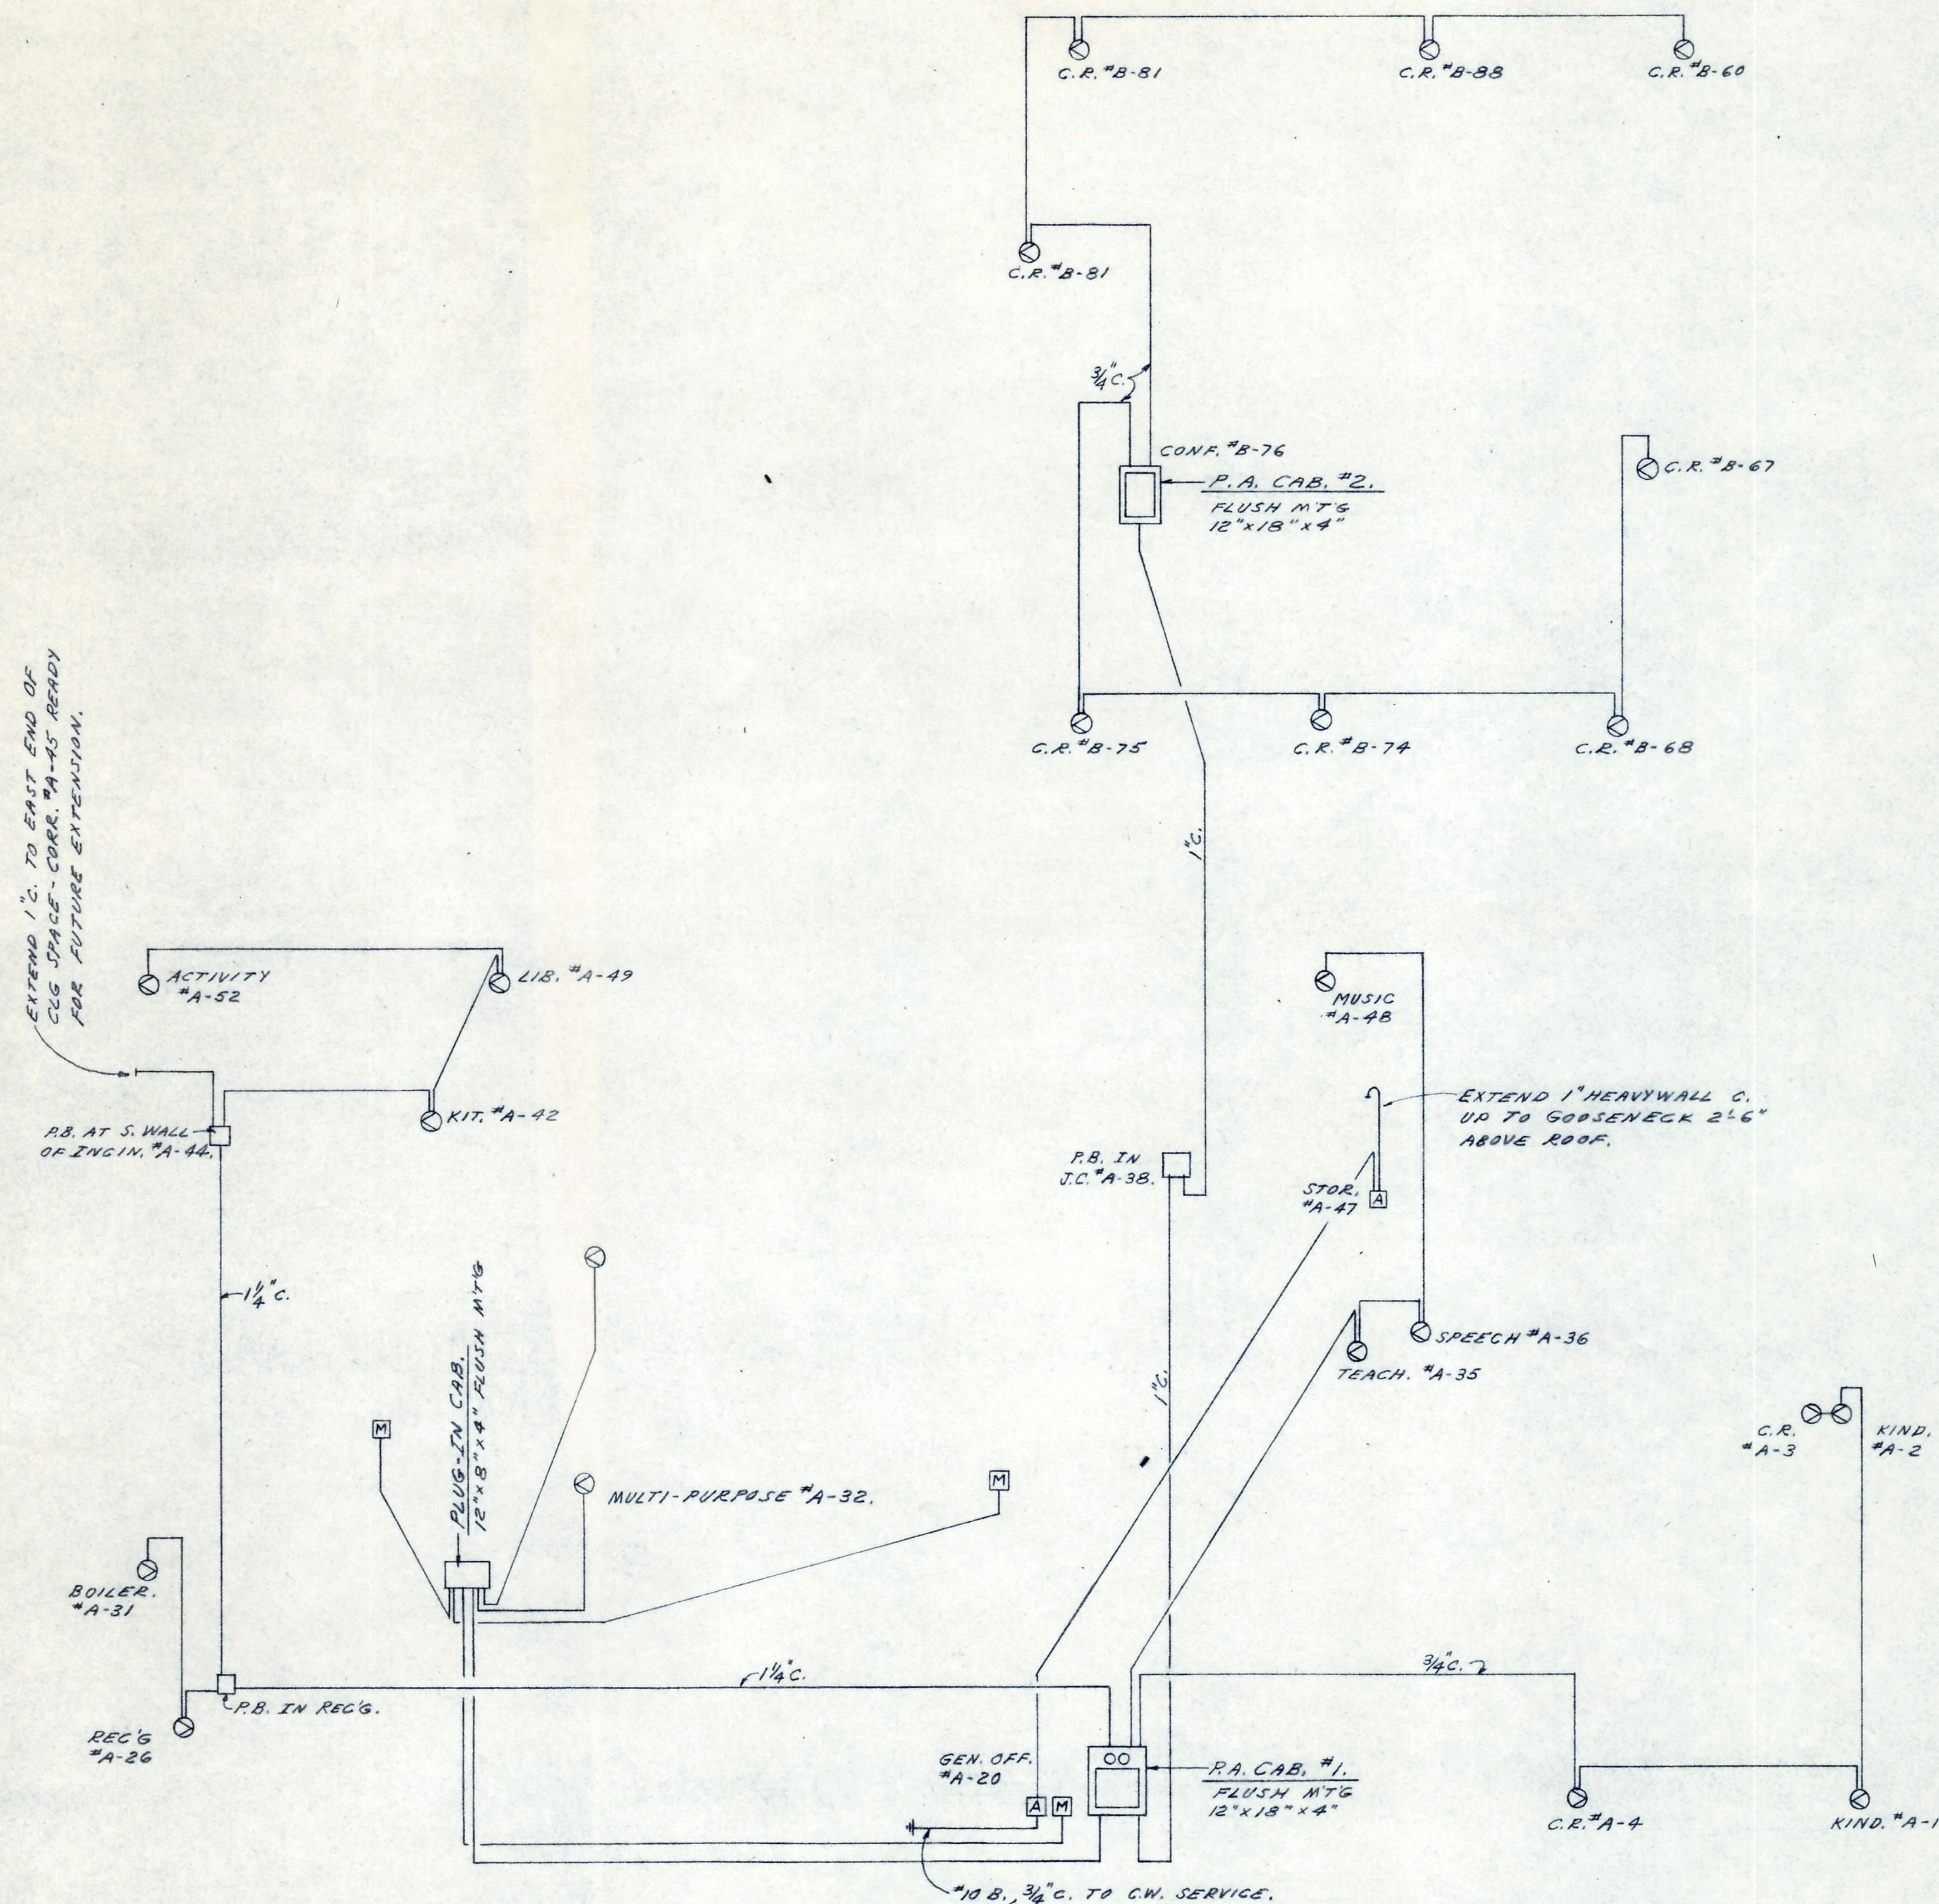

SOUND SYSTEM CONDUIT DIAGRAM
NO SCALE

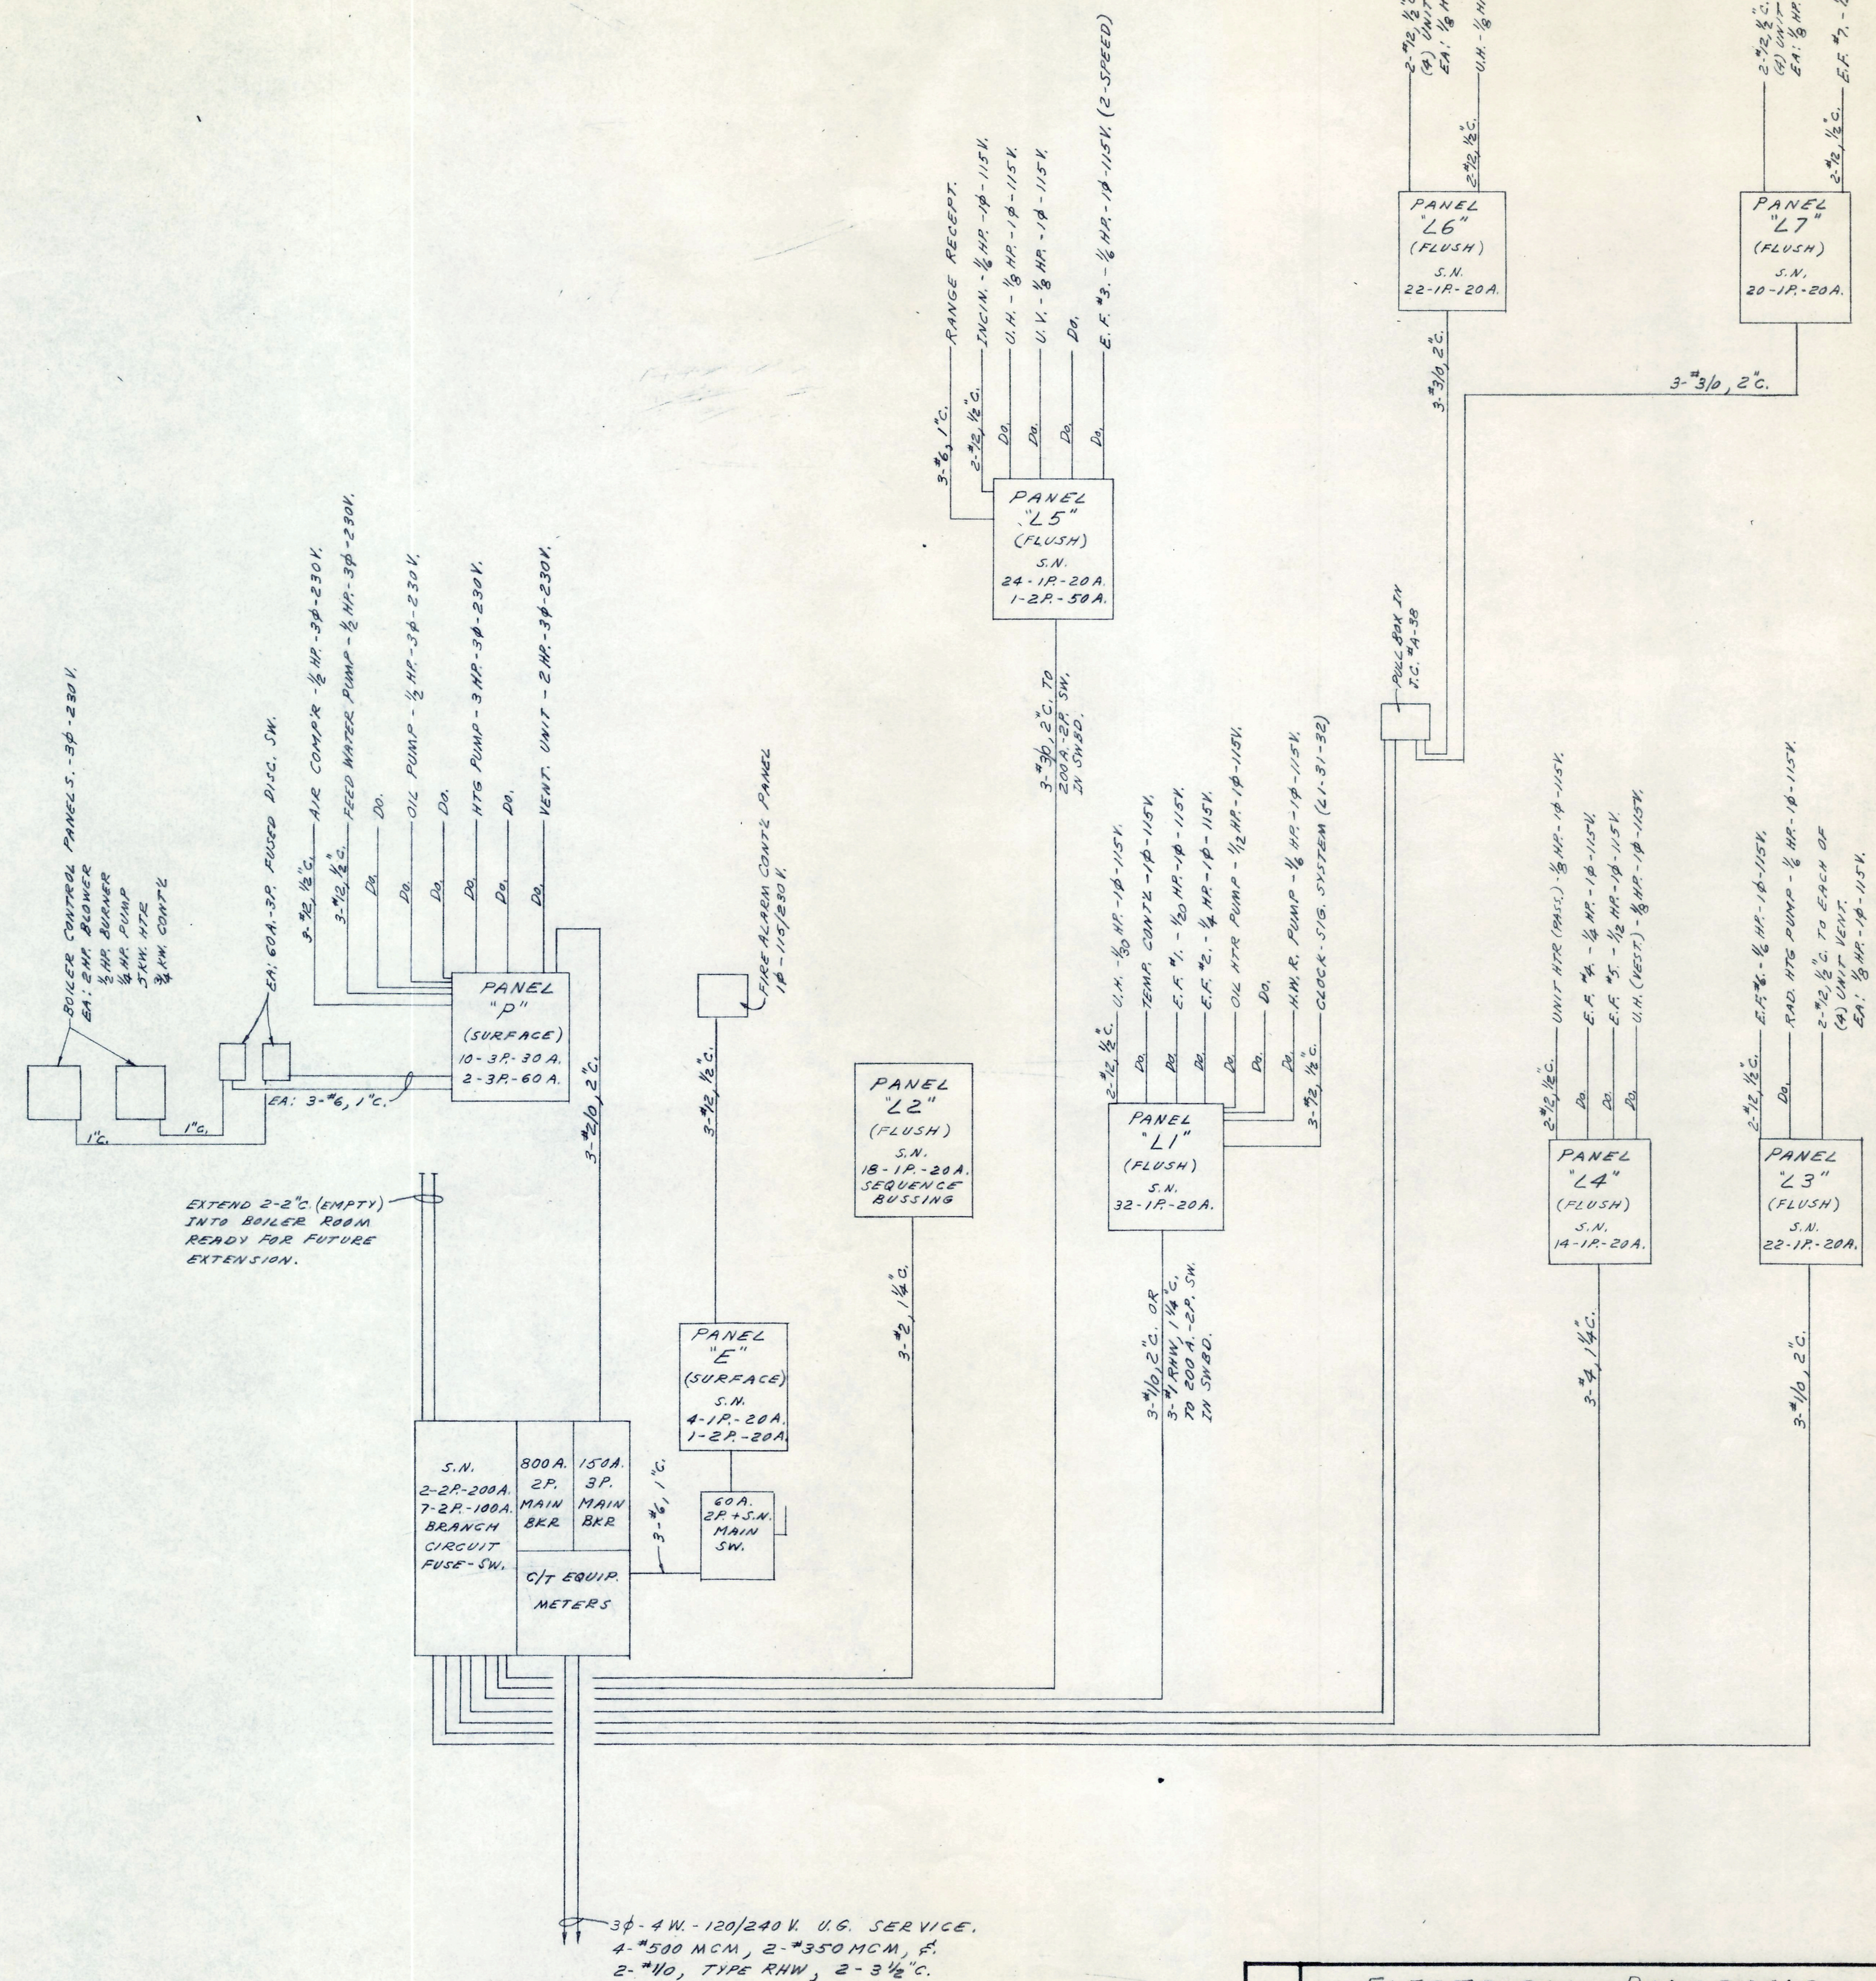

SCHEMATIC WIRING DIAGRAM
NO SCALE

APPROVED BY <i>Harry L. Holman</i>	<i>ELECTRICAL DIAGRAMS</i>		FILE NO.
	DATE 2-26-60	NEW ELEMENTARY SCHOOL, SECTION 9	1480
	REVISED	FOR	
		LIVONIA PUBLIC SCHOOLS SCHOOL DISTRICT	
	WAYNE COUNTY, MICHIGAN		
	EBERLE M. SMITH ASSOC., INC.		SHEET NO.
DRAWN BY HLM	ARCHITECTS ENGINEERS		E-4
ROOM 626 - 153 EAST ELIZABETH STREET - DETROIT 1. - WOODWARD 5-8180			