


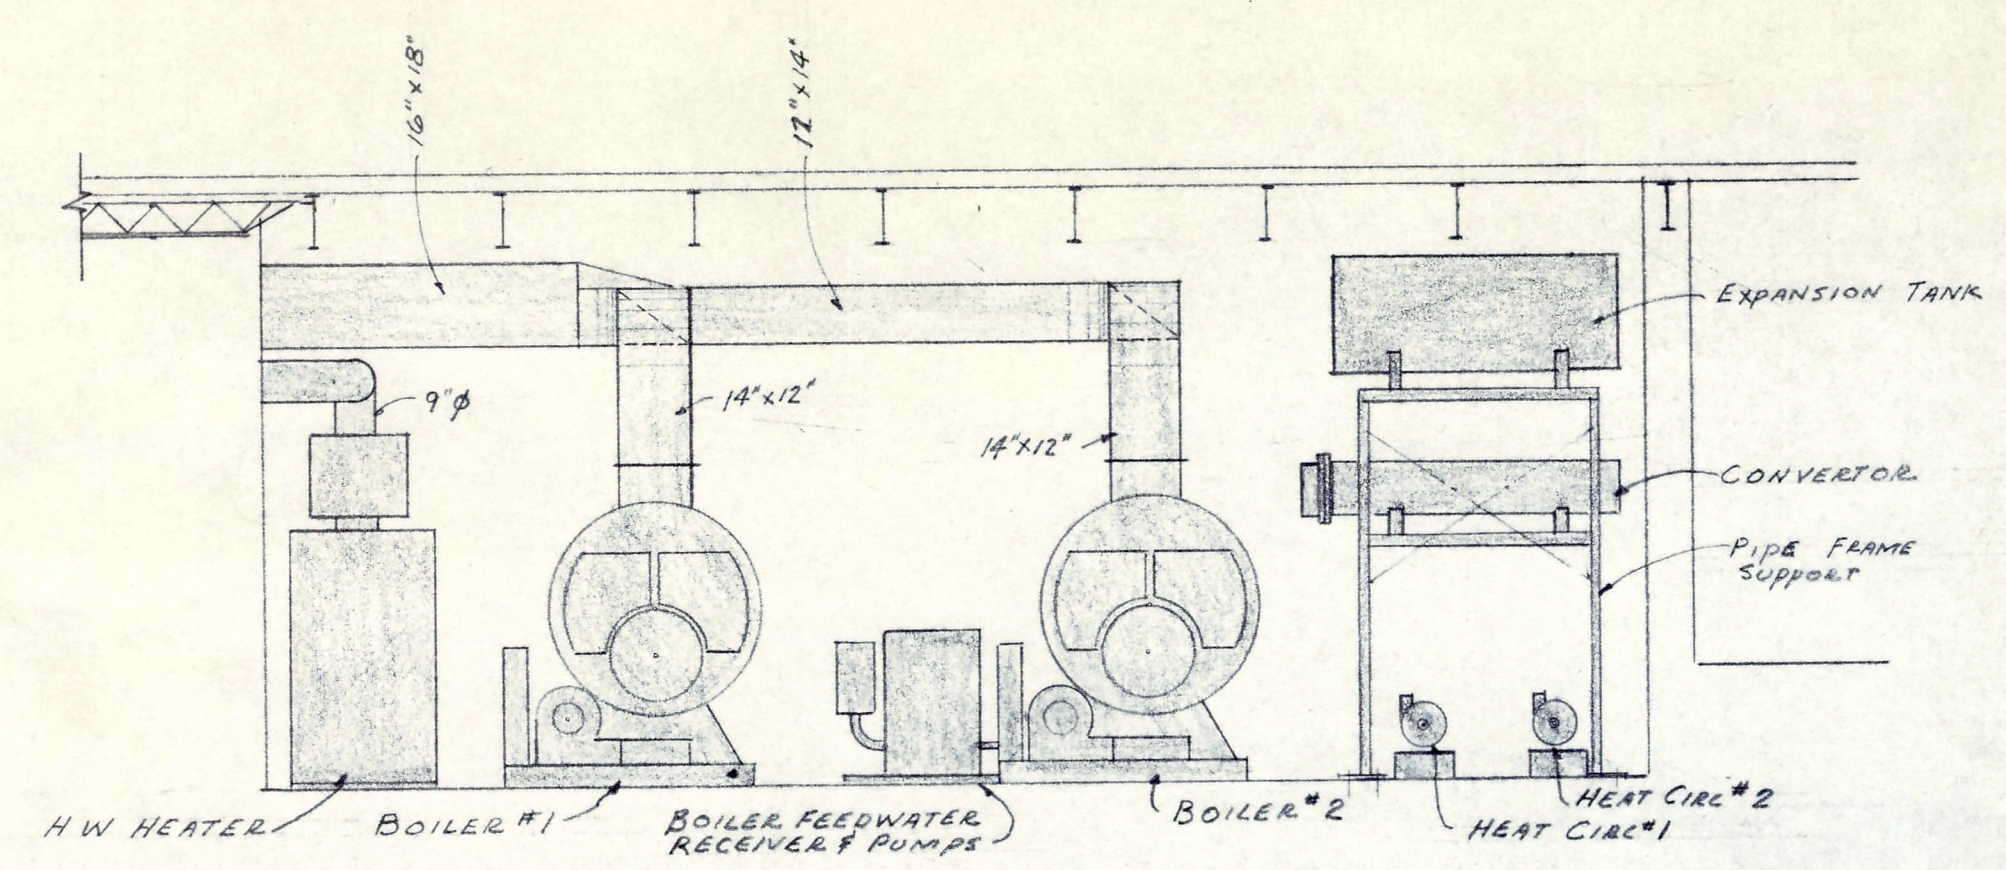

SECTION "A-M3"
SCALE 1/4" = 1'-0"



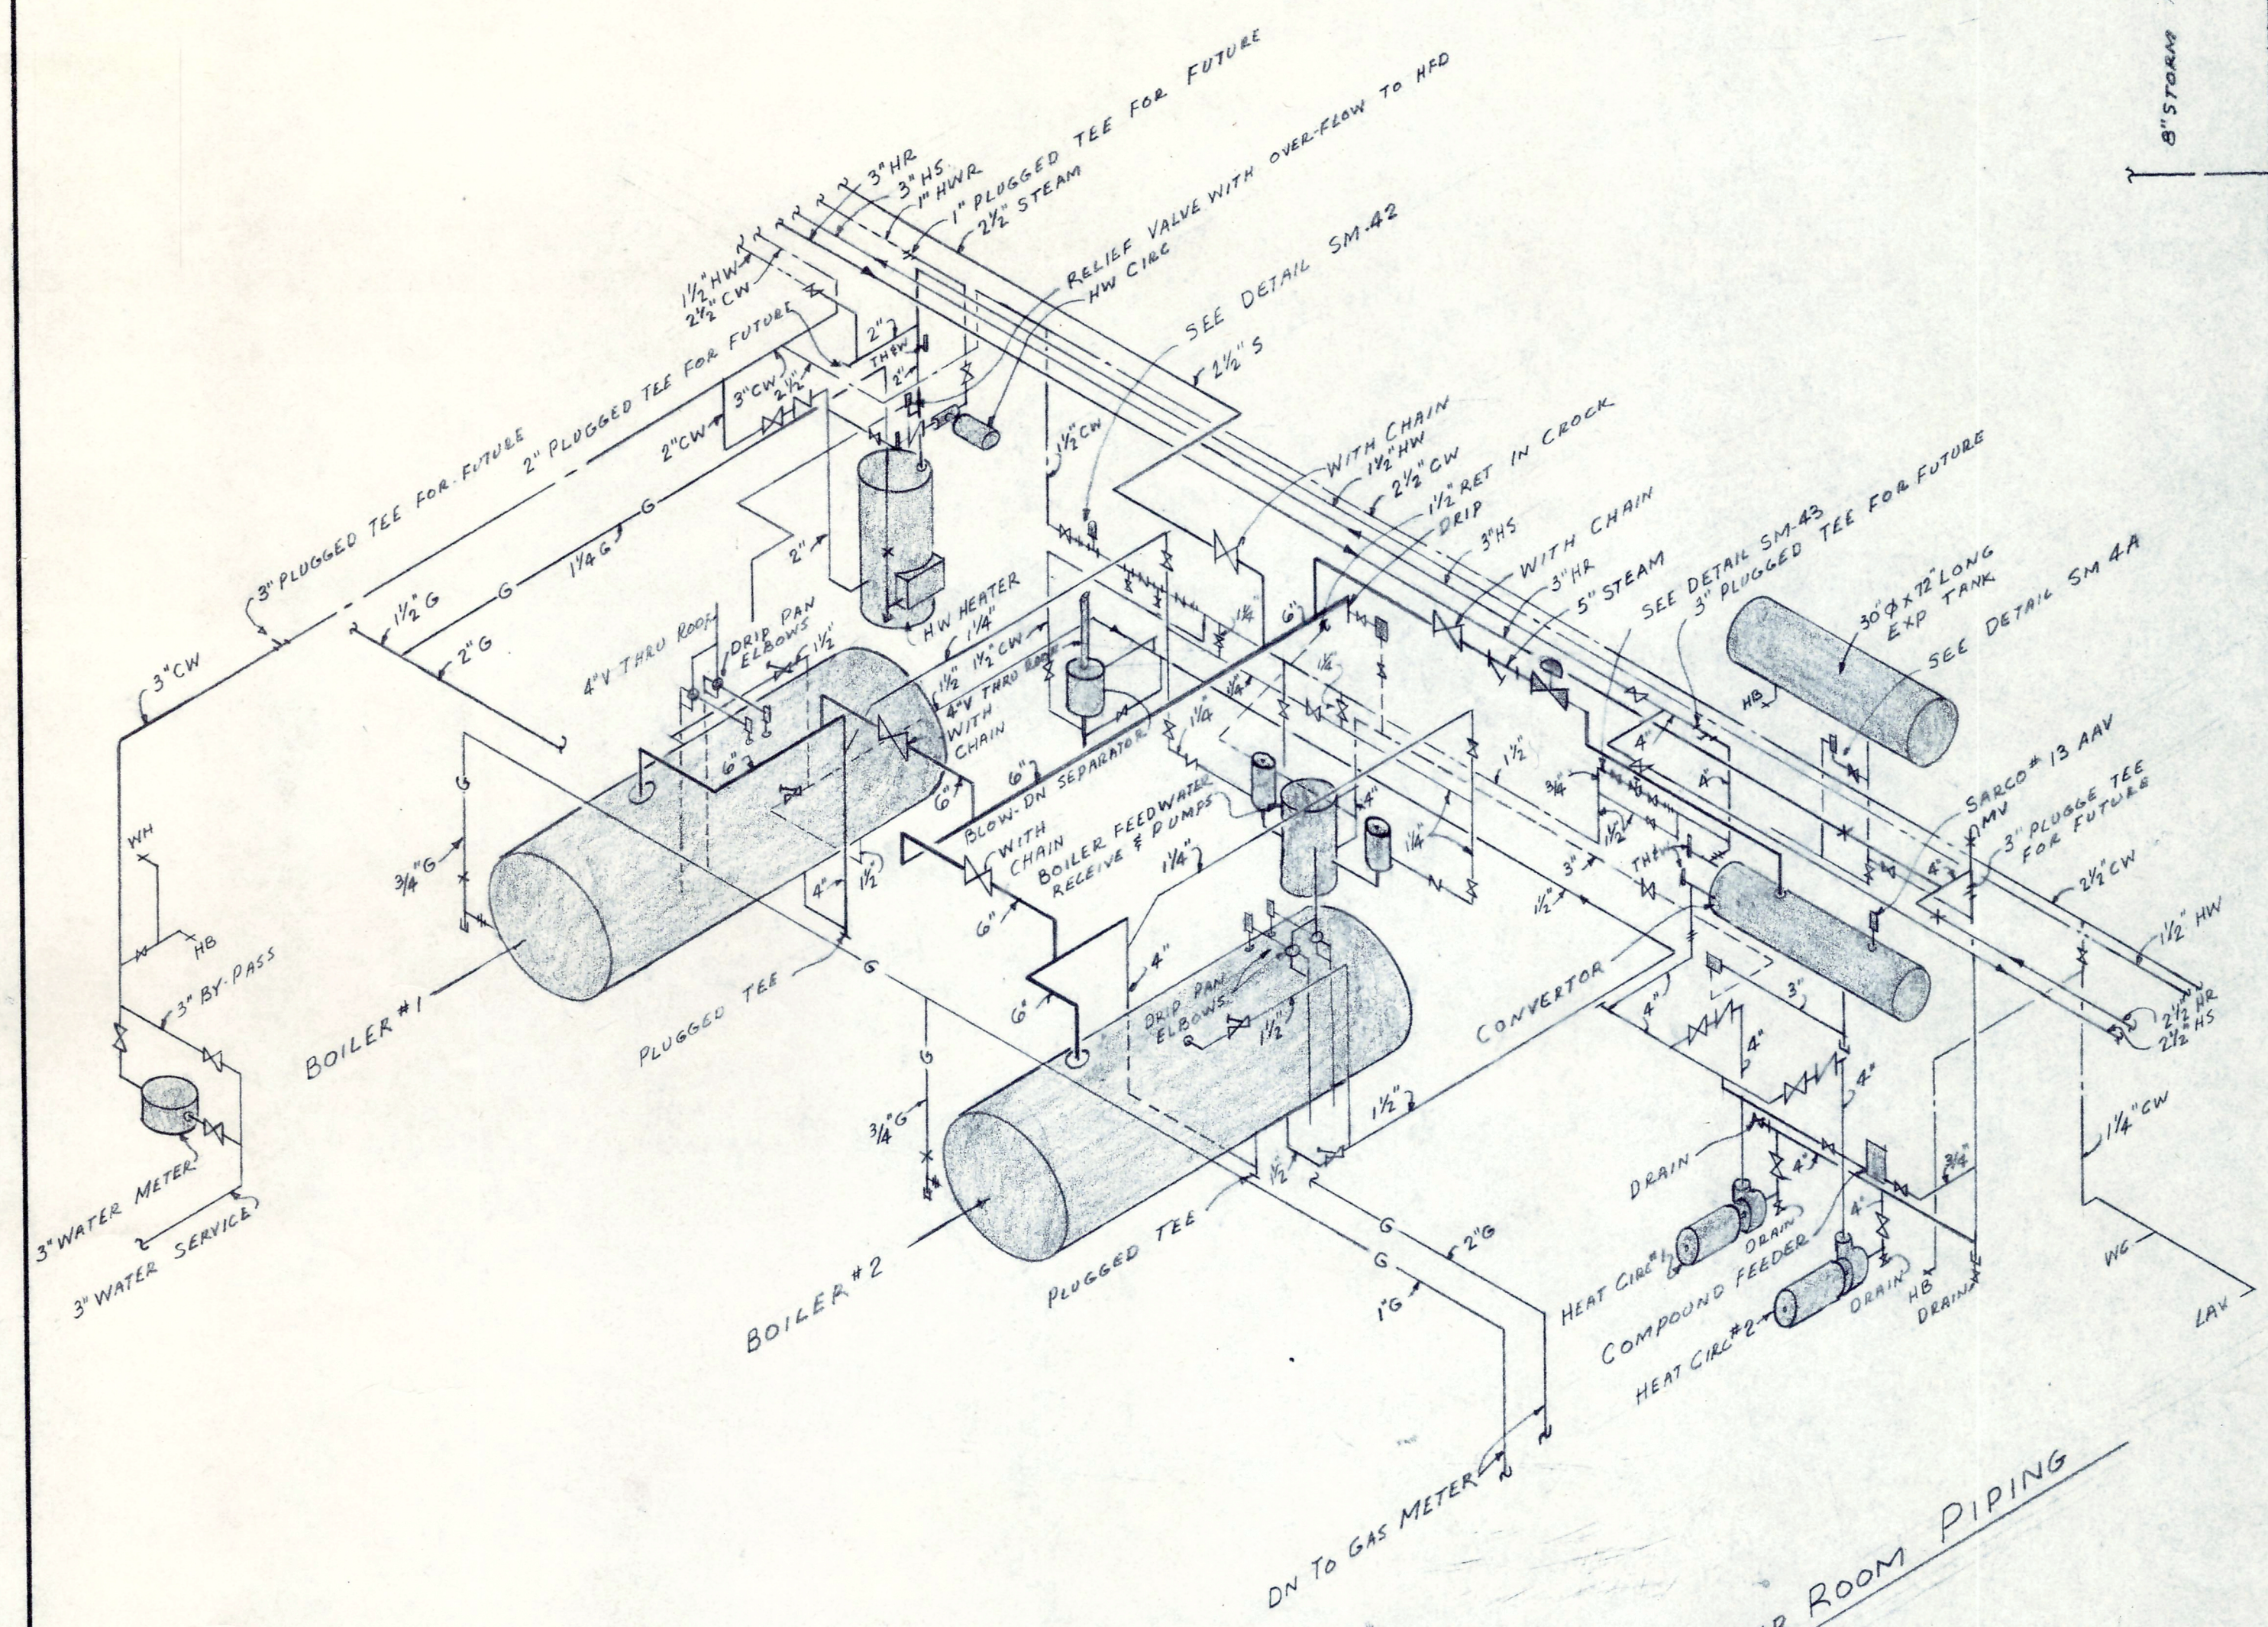


DIAGRAM OF BOILER ROOM PIPING
NO SCALE

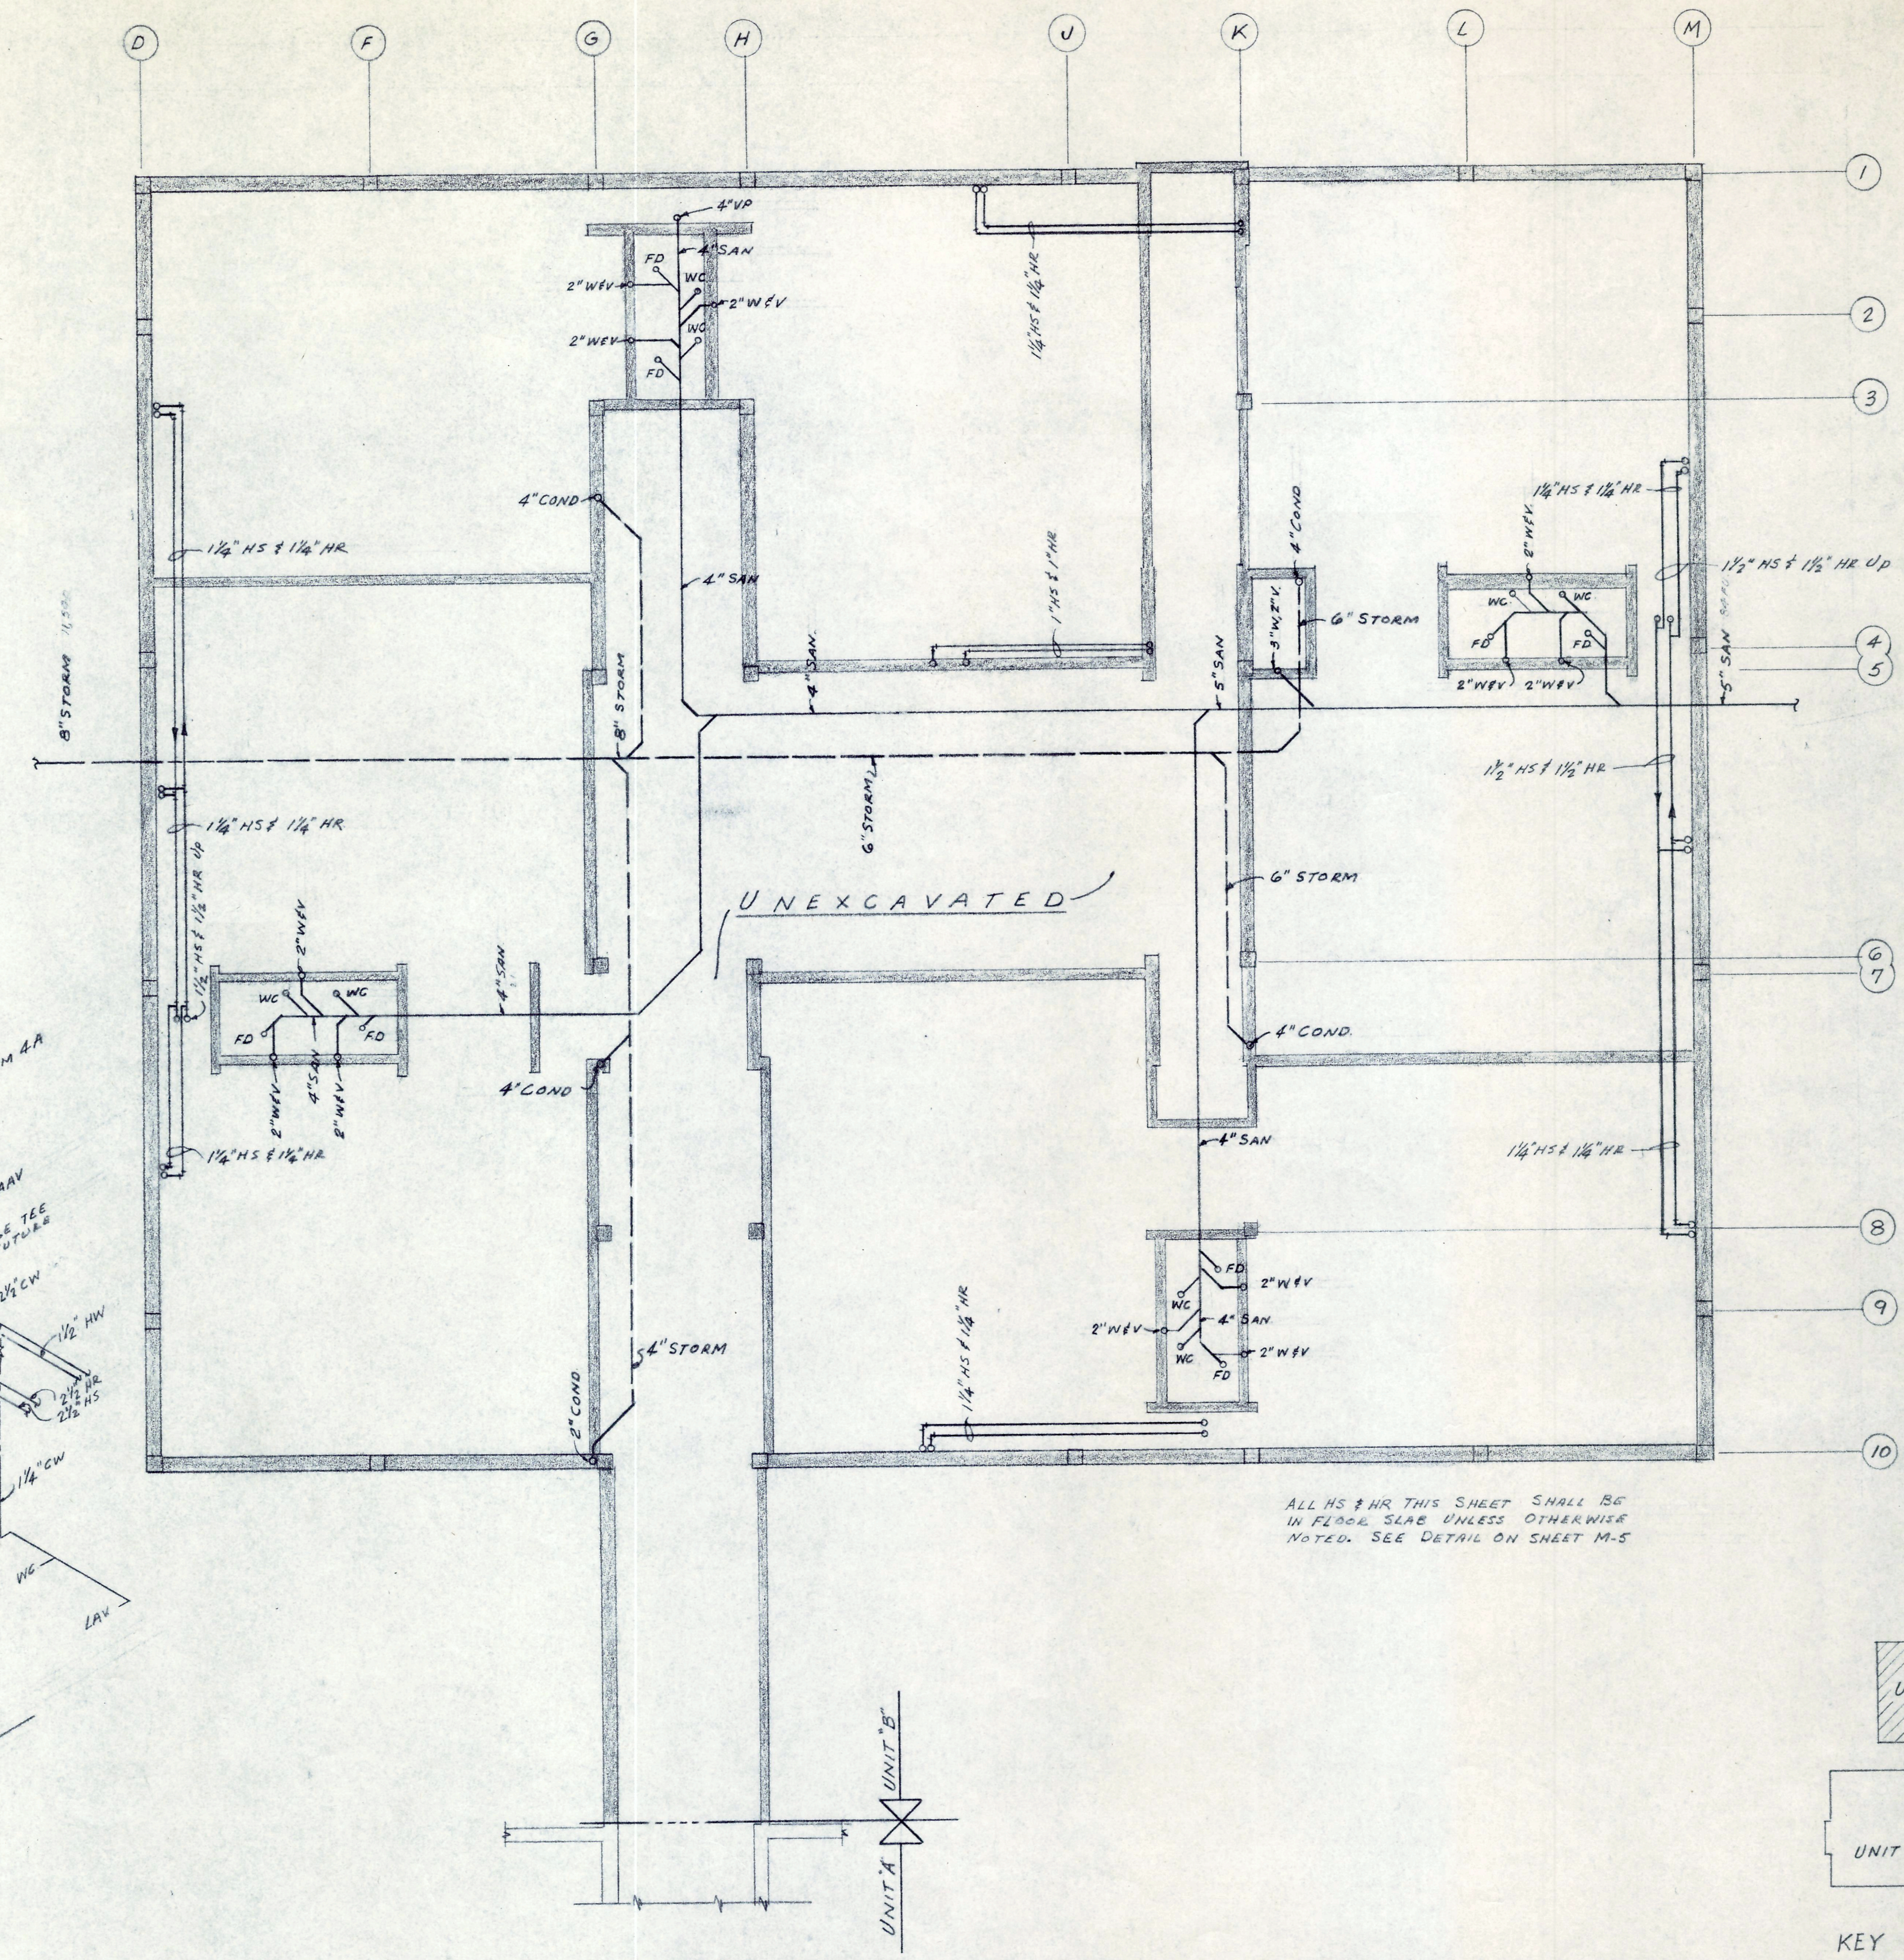





ALL HS & HR THIS SHEET SHALL BE
IN FLOOR SLAB UNLESS OTHERWISE
NOTED. SEE DETAIL ON SHEET M-5

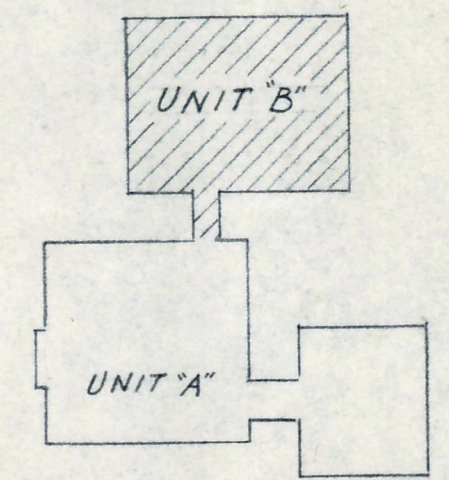

KEY PLAN

MECHANICAL FOUNDATION PLAN-UNIT "B"
SCALE 1/8" = 1'-0"

MECHANICAL FOUNDATION PLAN-UNIT "B"			
APPROVED BY <i>G. M. Smith</i>	DATE 2-5-60	NEW ELEMENTARY SCHOOL SECTION 9 FOR LIVONIA PUBLIC SCHOOLS SCHOOL DISTRICT WAYNE COUNTY, MICHIGAN	FILE NO.
	REVISID		1480
	DRAWN BY E. J. JONES	EBERLE M. SMITH ASSOC., INC. ARCHITECTS ENGINEERS	SHEET NO. M-3
ROOM 626 • 153 EAST ELIZABETH STREET - DETROIT 1. - WOODWARD 5-8180			

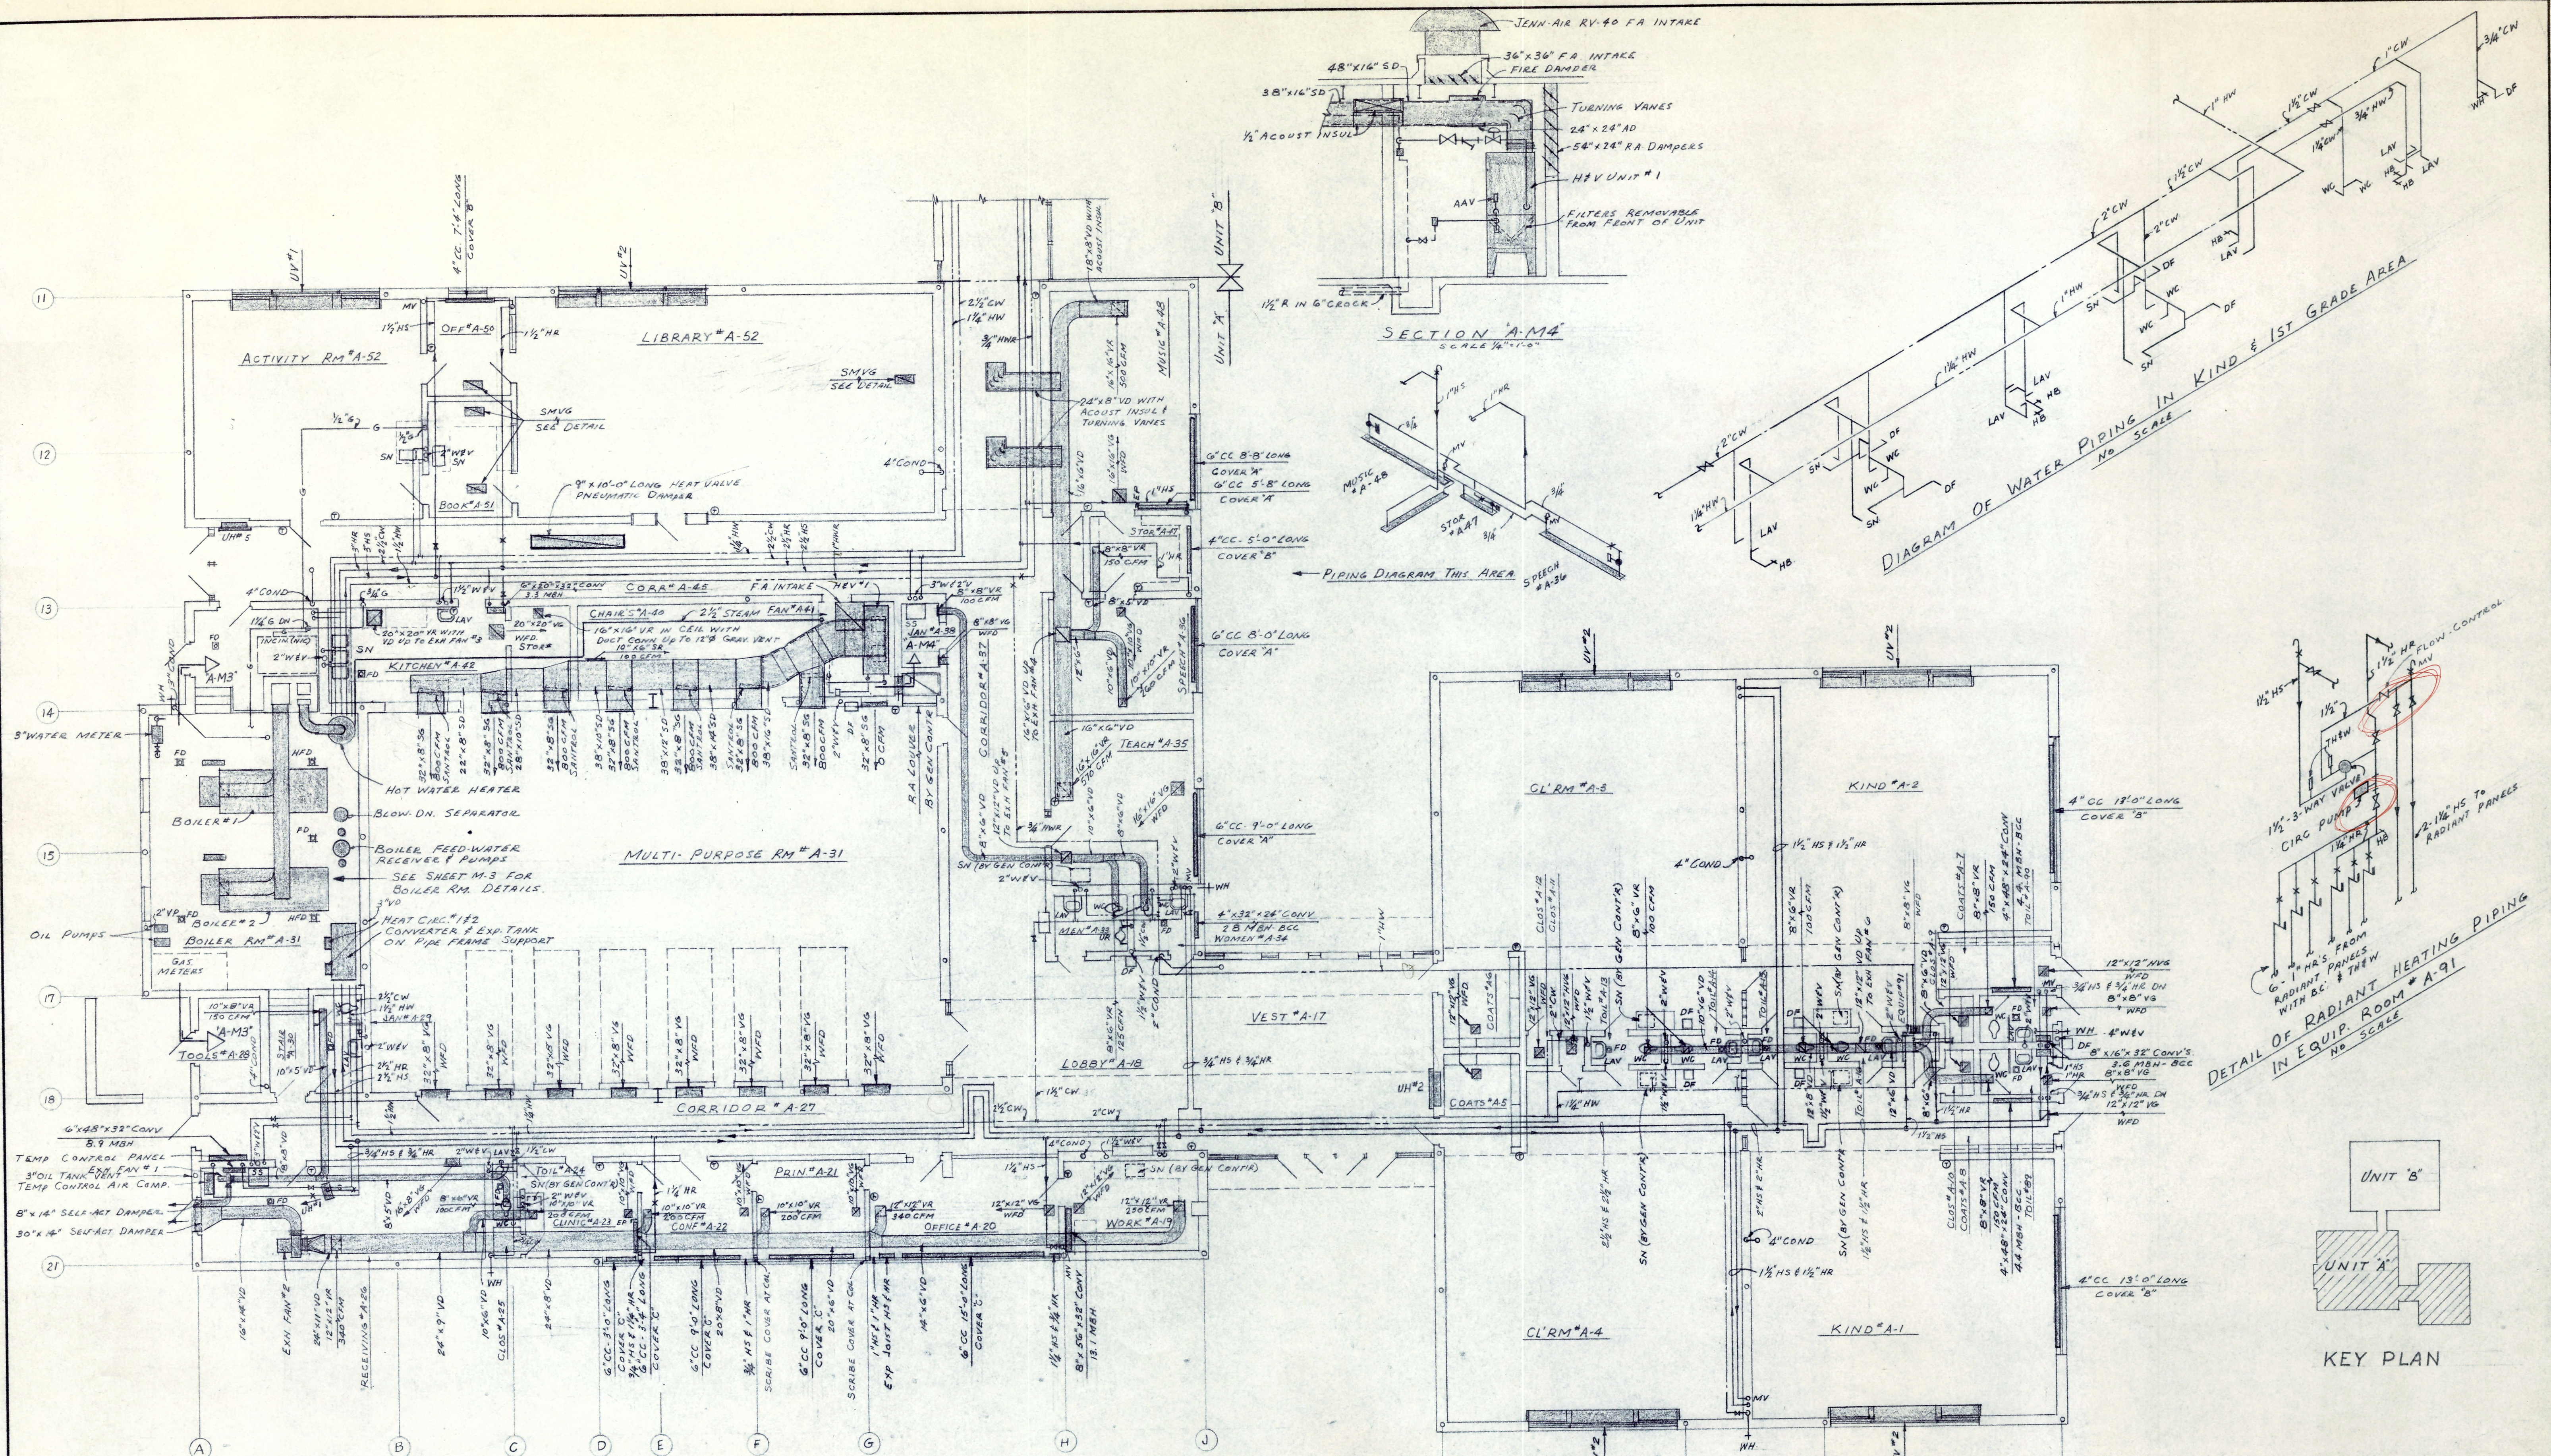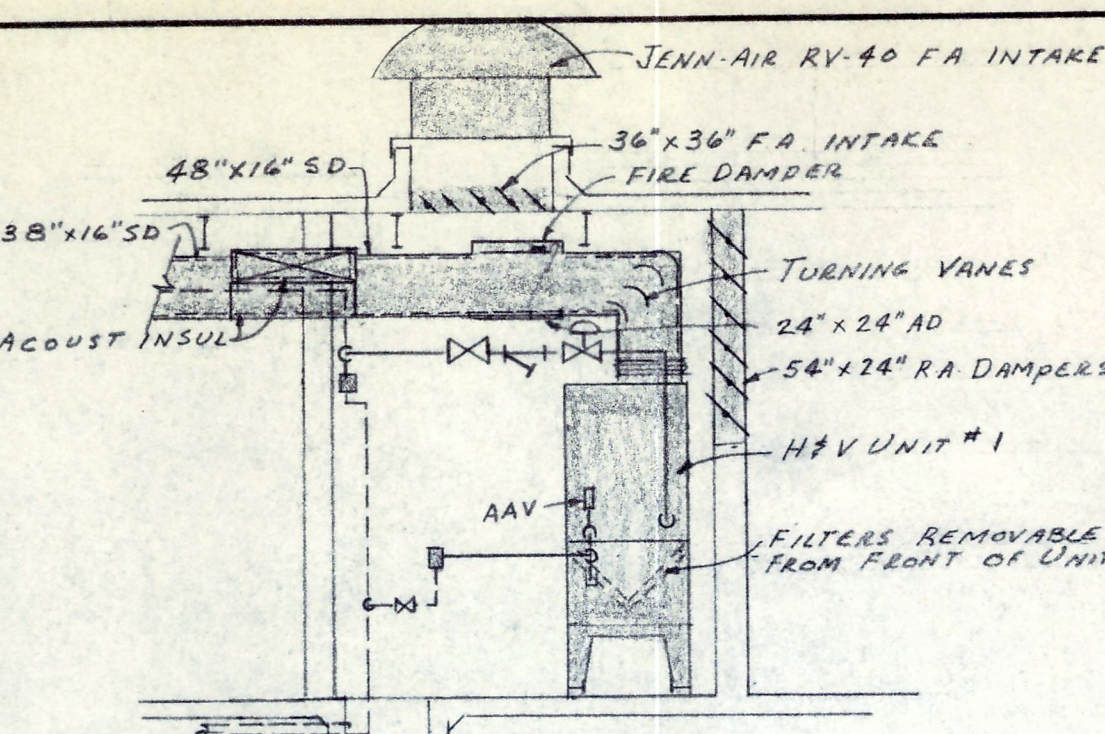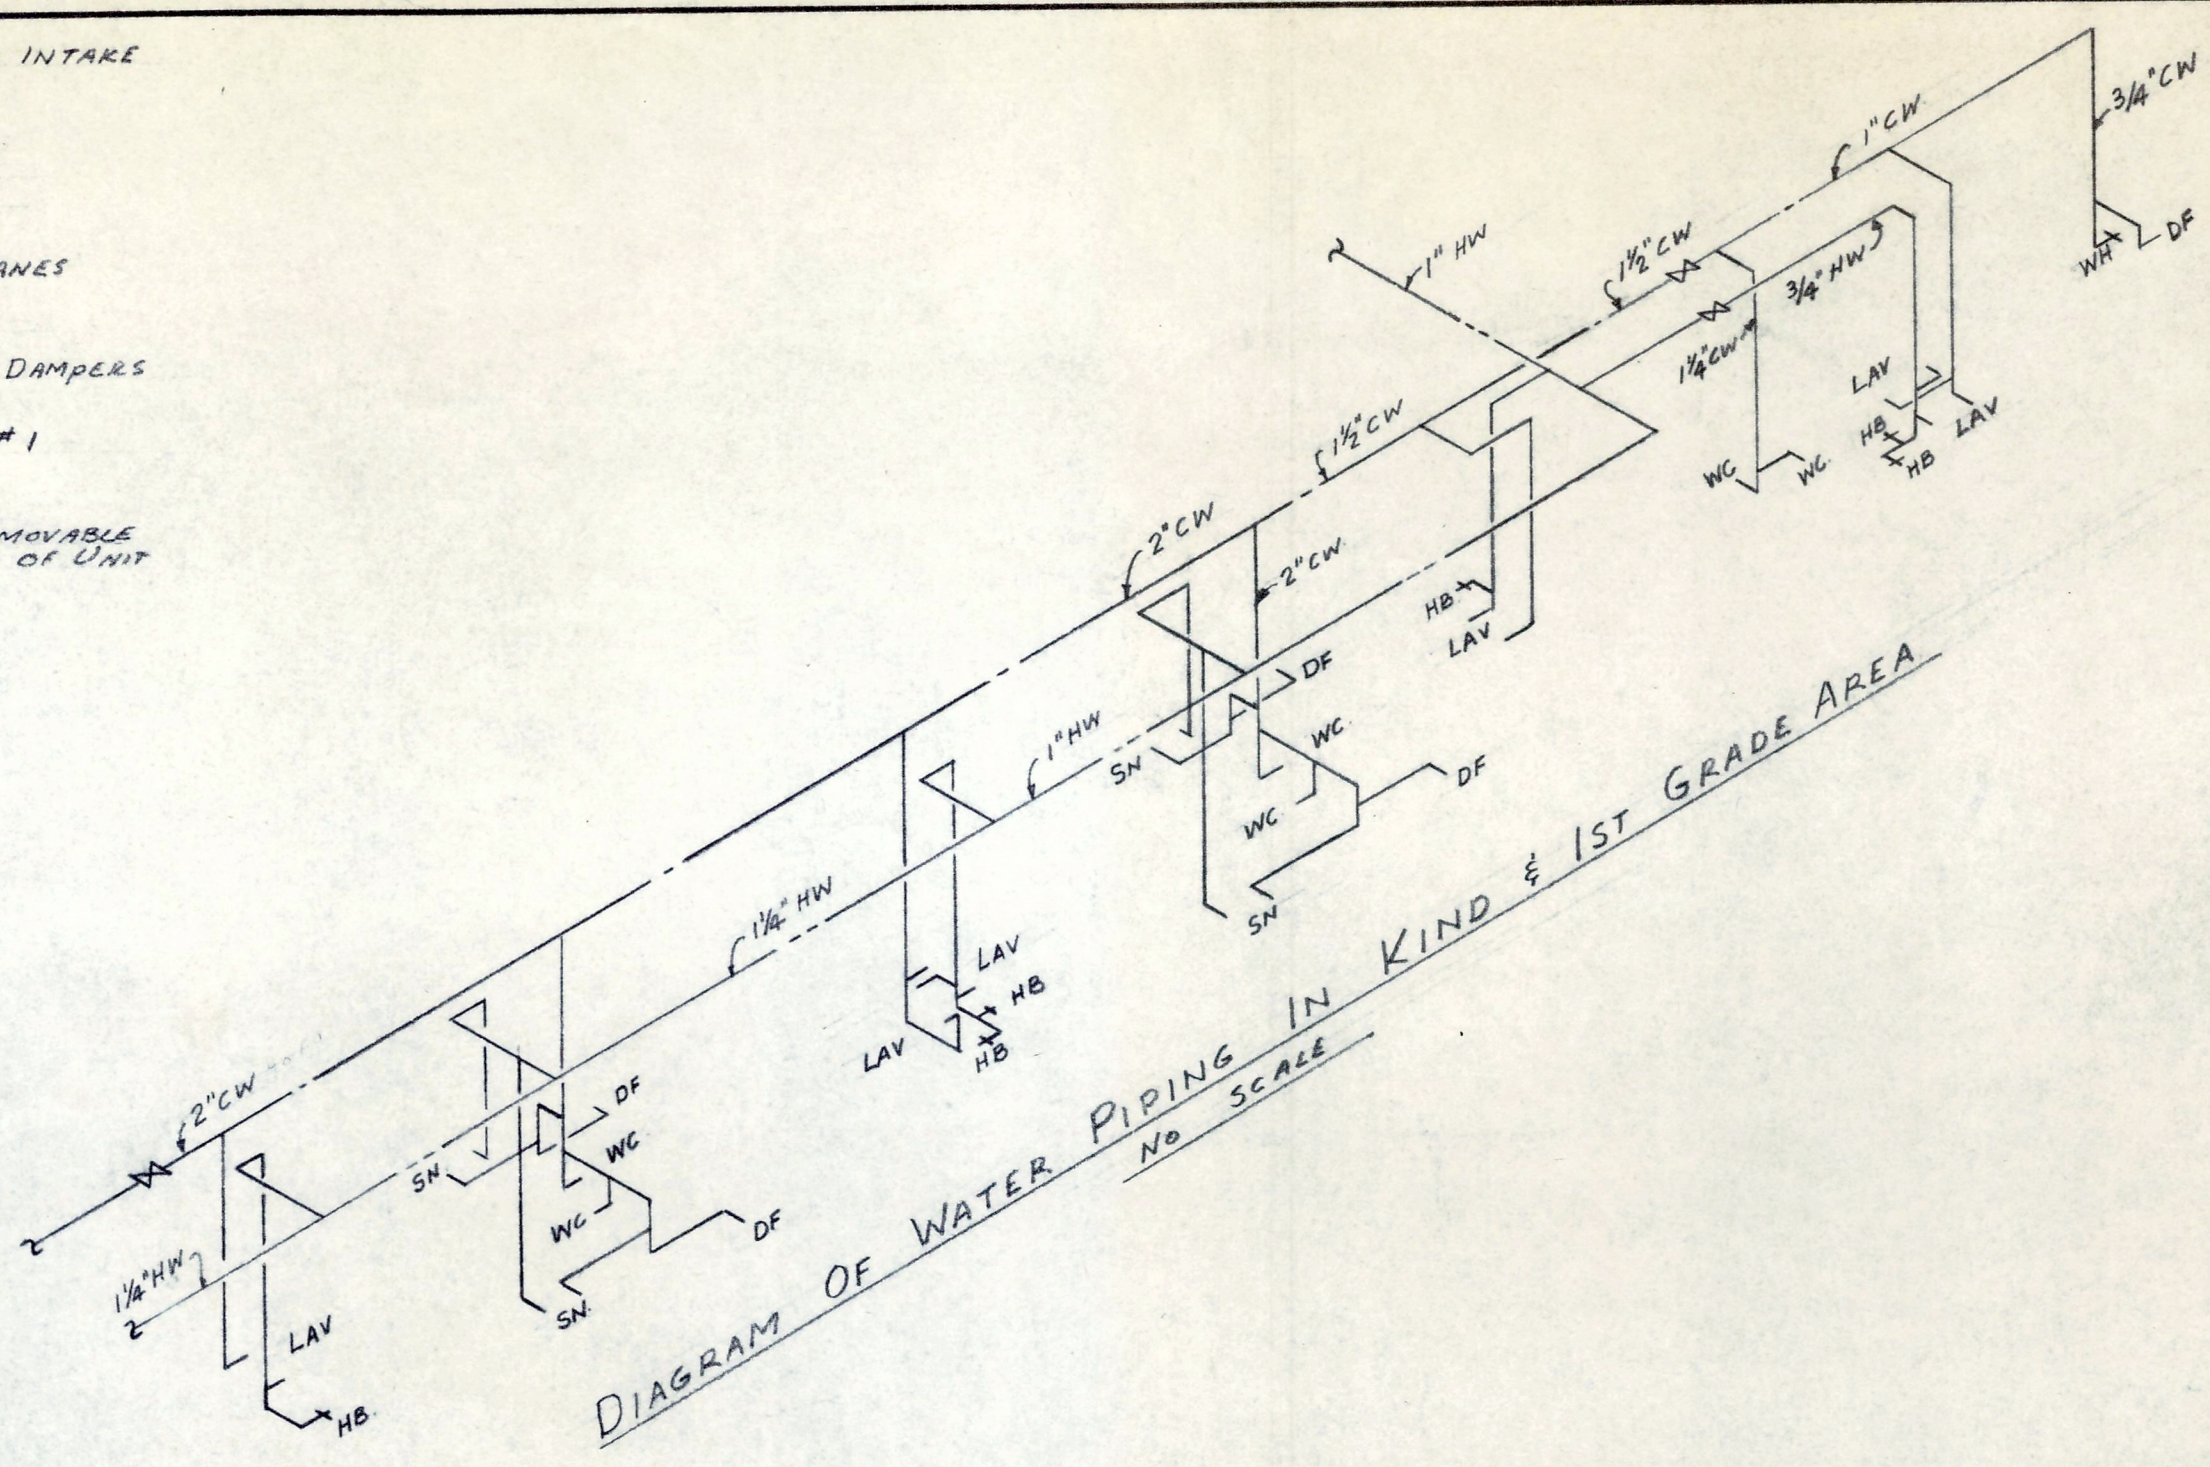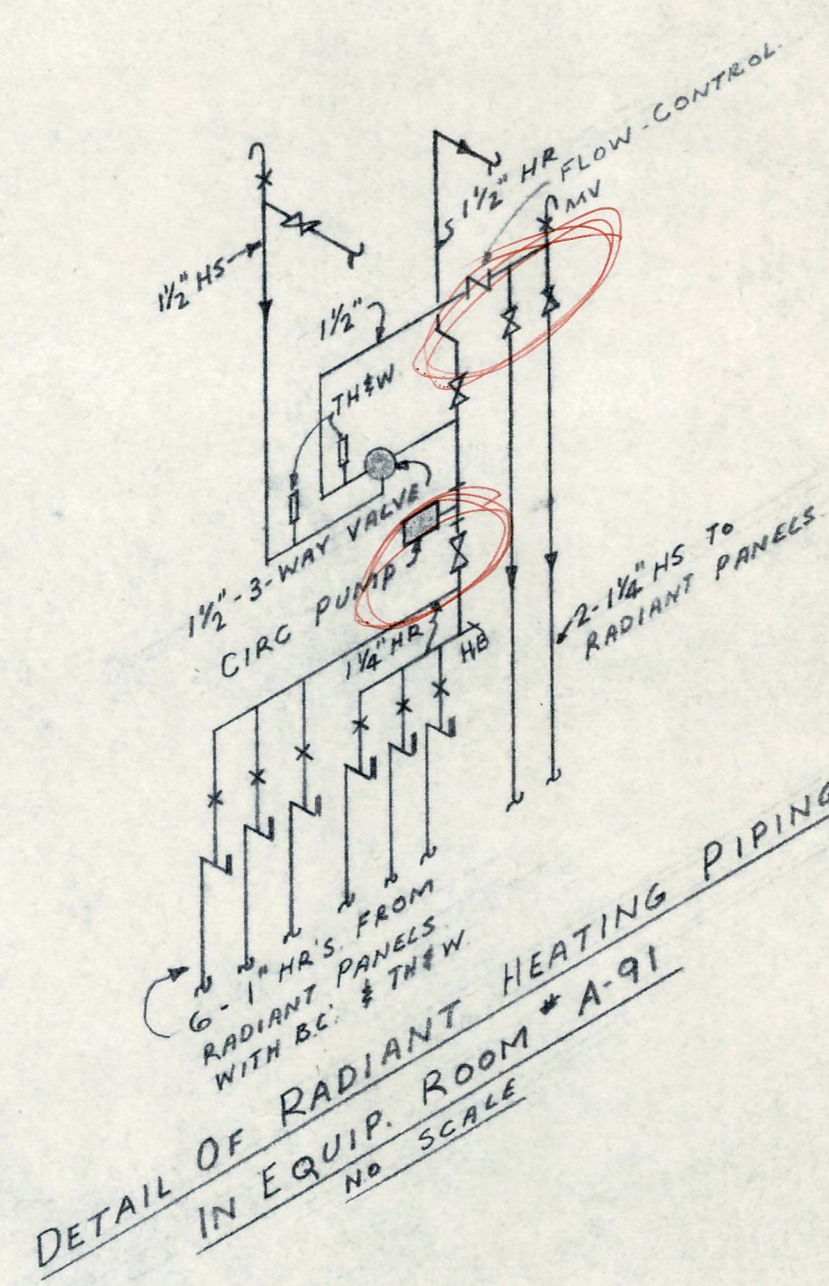

MECHANICAL FLOOR PLAN-UNIT "A"
SCALE 1/8"=1'-0"

MECHANICAL FLOOR PLAN-UNIT "A"				FILE NO.
APPROVED BY <i>J. M. Deppa</i>	203180	NEW ELEMENTARY SCHOOL SECTION 9		1480
	REVISED	FOR		
	LIVONIA PUBLIC SCHOOLS SCHOOL DISTRICT			
		WAYNE COUNTY, MICHIGAN		
	EBERLE M. SMITH ASSOC., INC.			SHEET NO.
	ARCHITECTS ENGINEERS			M-4
	ROOM 626 • 153 EAST ELIZABETH STREET • DETROIT 1, • WOODWARD 5-8190			

APPROVED BY <i>H. H. Gagnier.</i>	MECHANICAL FLOOR PLAN - UNIT "B"		
	DATE 2-5-60	NEW ELEMENTARY SCHOOL SECTION 9	FILE NO.
	REVISED	FOR LIVONIA PUBLIC SCHOOLS SCHOOL DISTRICT WAYNE COUNTY, MICHIGAN	1480
	DRAWN BY BOSS	EBERLE M. SMITH ASSOC., INC. ARCHITECTS ENGINEERS	SHEET NO. M-5
	ROOM 626 - 153 EAST ELIZABETH STREET - DETROIT 1. - WOODWARD 5-8190		