




TMP Associates, Inc.
Architects Engineers Planners
1191 W. Square Lake Rd.
P.O. Box 289
Bloomfield Hills, Mich.
48303-0289
(313) 338-4561

project title
**Marshall
Elementary
Renovation**

Livonia
Public Schools

sheet title
**Composite
Plan - Electrical**

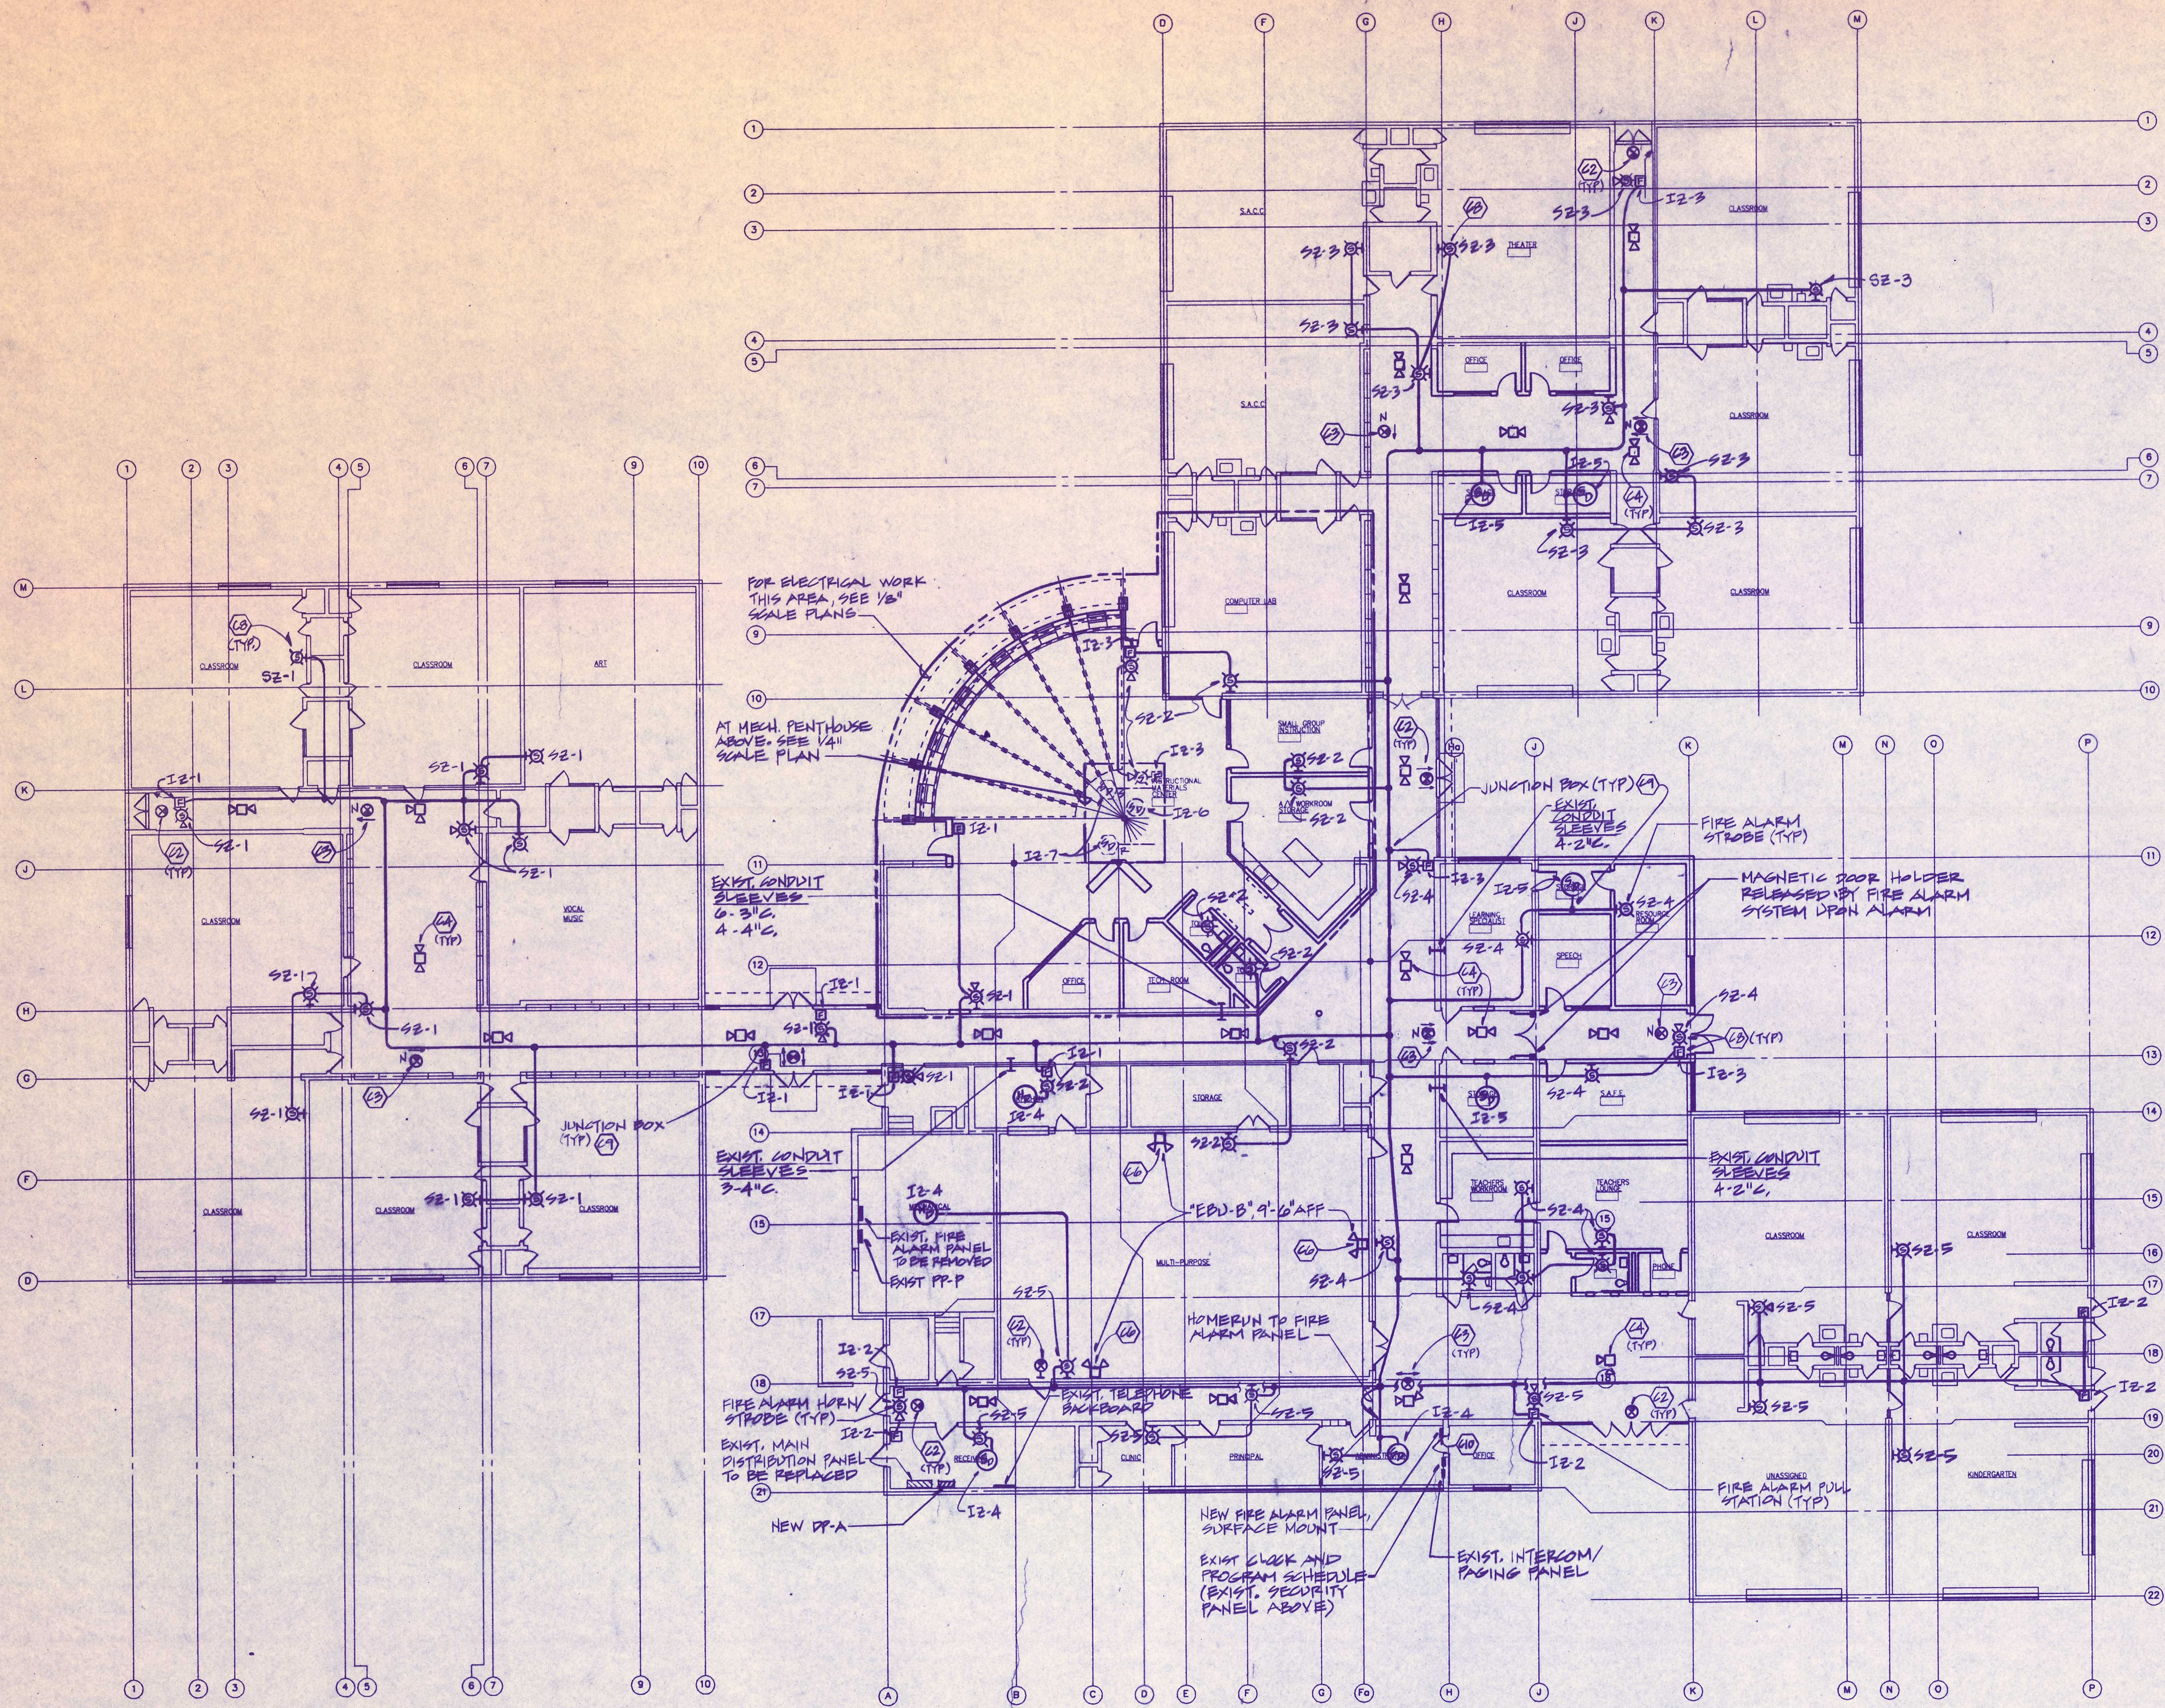

FIRE ALARM SYSTEM WIRING

INITIATING ZONE (I2) SERVING PULL STATION OR WATER FLOW.	2#18
INITIATING ZONE (I2) SERVING SMOKE DETECTOR, HEAT DETECTOR, OR DUCT SMOKE DETECTOR.	2#18 ALARM 2#16 POWER
SUPERVISORY ZONE SERVING TAMPER SWITCH.	2#18
DOOR HOLD OPEN ELECTRO-MAGNETS	2#16
SIGNAL ZONE (S2) SERVING HORN, STROBE, OR HORN/STROBE.	2#14

NOTES:

- ALL WIRING SHALL BE INSTALLED IN CONDUIT OR WIREMOLD RACEWAY AS INDICATED OR SPECIFIED. MINIMUM SIZE CONDUIT 1/2". CONDUIT SERVING MAIN CORRIDORS SHALL BE 1" CONDUIT MINIMUM.
- INSTALL AN END OF LINE DEVICE FOR LAST DEVICE ON INITIATING SIGNAL OR SUPERVISORY CIRCUIT.
- EXACT SYSTEM WIRING SHALL BE IN ACCORDANCE WITH MANUFACTURER'S WIRING DIAGRAM. ELECTRICAL CONTRACTOR SHALL VERIFY WITH MANUFACTURER PRIOR TO INSTALLING ANY SYSTEM RACEWAY OR WIRING.
- FOR TYPICAL HORN/STROBE AND PULLSTATION MOUNTING DETAILS, SEE TYP. WIREWAY FEED DETAIL, SHT. E4.1.

COMPOSITE PLAN - ELECTRICAL
SCALE: 1/8" = 1'-0"

ELECTRICAL SYMBOL LIST	
SYMBOL	DESCRIPTION
[Symbol]	2'x4' FLUORESCENT LIGHT FIXTURE
[Symbol]	FLUORESCENT LIGHT FIXTURE, TYPE AS INDICATED
[Symbol]	DOWNLIGHT, TYPE AS INDICATED
[Symbol]	NIGHT LIGHT FIXTURE
[Symbol]	EMERGENCY BATTERY UNIT
[Symbol]	EXIT LIGHT FIXTURE (SHADED AREA INDICATES FACE OF FIXTURE). N = NEW
[Symbol]	CALL BUTTON
[Symbol]	SINGLE POLE SWITCH
[Symbol]	THREE WAY SWITCH
[Symbol]	DIMMER SWITCH
[Symbol]	DUCT SMOKE DETECTOR (S= SUPPLY, R= RETURN)
[Symbol]	DUPLEX RECEPTACLE
[Symbol]	DOUBLE DUPLEX RECEPTACLE
[Symbol]	SPECIAL RECEPTACLE
[Symbol]	HARDWIRED EQUIPMENT CONNECTION
[Symbol]	WIREWAY WITH DEVICES INDICATED
[Symbol]	CLOCK
[Symbol]	SPEAKER
[Symbol]	COMBINATION CLOCK/SPEAKER
[Symbol]	TELEVISION OUTLET
[Symbol]	SCHEDULE BELL
[Symbol]	LOW VOLTAGE/ DATA OUTLET
[Symbol]	TELEPHONE OUTLET
[Symbol]	UNDERFLOOR DUCT POWER AND LOW VOLTAGE PLUGS WITH ACTIVATION FITTING INDICATED
[Symbol]	UNDERFLOOR DUCT 120V, DUPLEX RECEPTACLE AND LOW VOLTAGE OUTLET
[Symbol]	FIRE ALARM PULL STATION
[Symbol]	FIRE ALARM HORN (EXISTING)
[Symbol]	FIRE ALARM STROBE
[Symbol]	FIRE ALARM HORN/ STROBE
[Symbol]	FIRE ALARM CEILING MOUNTED JUNCTION BOX
[Symbol]	SMOKE DETECTOR
[Symbol]	HEAT DETECTOR
[Symbol]	PANELBOARD
[Symbol]	JUNCTION BOX
[Symbol]	MANUAL MOTOR STARTER (P=PILOT LIGHT)
[Symbol]	DISCONNECT SWITCH
[Symbol]	COMBINATION MAGNETIC MOTOR STARTER
[Symbol]	SINGLE PHASE MOTOR
[Symbol]	THREE PHASE MOTOR
[Symbol]	TRANSFORMER
[Symbol]	INDICATES NOTE DESIGNATION
[Symbol]	ABOVE FINISHED FLOOR
[Symbol]	GROUND FAULT INTERRUPTER
[Symbol]	WEATHERPROOFED
[Symbol]	UNIT HEATER
[Symbol]	AIR HANDLING UNIT
[Symbol]	AIR COOLED CONDENSING UNIT
[Symbol]	LIGHTING PANEL
[Symbol]	RECEPTACLE PANEL
[Symbol]	MAIN DISTRIBUTION PANEL
[Symbol]	DISTRIBUTION PANEL
[Symbol]	POWER PANEL

COMPOSITE NOTES

- IN GENERAL, EXISTING CORRIDORS UTILIZE LAY-IN CEILINGS. UNLESS OTHERWISE INDICATED, ALL NEW CONDUIT INSTALLED WITHIN EXISTING SCHOOL SHALL BE CONCEALED ABOVE CEILINGS OR WITHIN WALL CONSTRUCTION. USE SURFACE WIREMOLD RACEWAY FOR VERTICAL DROP FROM CEILING SPACE TO STROBES, PULL STATIONS, ETC.
- REPLACE EXISTING EXIT LIGHT FIXTURE WITH NEW FIXTURE TYPE "XA" SINGLE FACE OR "XB" DOUBLE FACE AS INDICATED.
- NEW EXIT LIGHT FIXTURE, TYPE "XA" SINGLE FACE OR "XB" DOUBLE FACE AS INDICATED. NEW EXIT LIGHTS TO BE SERVED WITH 2 #12 IN RACEWAY FROM NEAREST EXISTING EXIT LIGHT OR EXIT LIGHTING BRANCH CIRCUIT.
- NEW EMERGENCY LIGHTING BATTERY UNIT, TYPE "EBU-A" UNLESS OTHERWISE INDICATED. MOUNT IN EXISTING LAYIN CEILING. INCLUDE IN THE ELECTRICAL BID, THE CUTTING OF EXISTING CEILING TILE AND INSTALLATION OF NEW GRID "G" AS REQUIRED TO FRAME UNIT.
- ALL EMERGENCY LIGHTING BATTERY UNITS TO BE SERVED FROM CONNECTION ON LINE SIDE OF LIGHT SWITCH SERVING NORMAL LIGHTING IN AREA, OR FROM THE EXISTING NIGHT LIGHT CIRCUIT WHERE APPLICABLE.
- PROVIDE METAL GAUGE GUARD ON NEW EMERGENCY BATTERY UNITS AT MULTI-PURPOSE AND GYMNASIUM.
- NEW FIRE ALARM SYSTEM SHALL BE INSTALLED, TESTED AND ADJUSTED PRIOR TO THE DEMOLITION OF EXISTING FIRE ALARM SYSTEM.
- ALL FIRE ALARM STROBES OR HORN STROBES, SHALL BE WALL MOUNTED AT 6'-8" AFF. ALL FIRE ALARM PULL STATIONS SHALL BE MOUNTED AT 48" AFF.
- THE INSIDE OF BOX AND COVER OF ALL JUNCTION BOXES (WITHOUT DEVICES) SERVING FIRE ALARM SYSTEM SHALL BE PAINTED RED.
- SEE TYPICAL FIRE ALARM PANEL FEED DETAIL FOR ROUTING OF WIRING TO NEW SURFACE MOUNTED FIRE ALARM PANEL.

8-24-92	BIDS
8-17-92	95% AMHEP REV.
00-00-89	ISSUE NAME
date	issued for
drawn	B.J.G.
checked	J.B.
approved	J.B.
job. no.	
92014	
sheet no.	
E2.1	

TMP

TMP Associates, Inc.
Architects Engineers Planners
1191 W. Square Lake Rd.
P.O. Box 289
Bloomfield Hills, Mich.
48303-0289
(313) 338-4561

BERRIGLIA ASSOCIATES, INC.
CONSULTING ENGINEERS
(313) 358-1000 • FAX (313) 358-1001
24001 Northwestern Hwy. • Suite 201
Southfield, Michigan 48034
BAJ NO. 92-1601

project title
**Marshall
Elementary
Renovation**


sheet title
**Electrical
Demolition
Plan - Zone "A"**

8-24-92 BJD
8-17-92 95% OWNER REV.
date issued for

drawn BJD
checked J.B.
approved J.B.

job no.
92014

sheet no.
E2.2

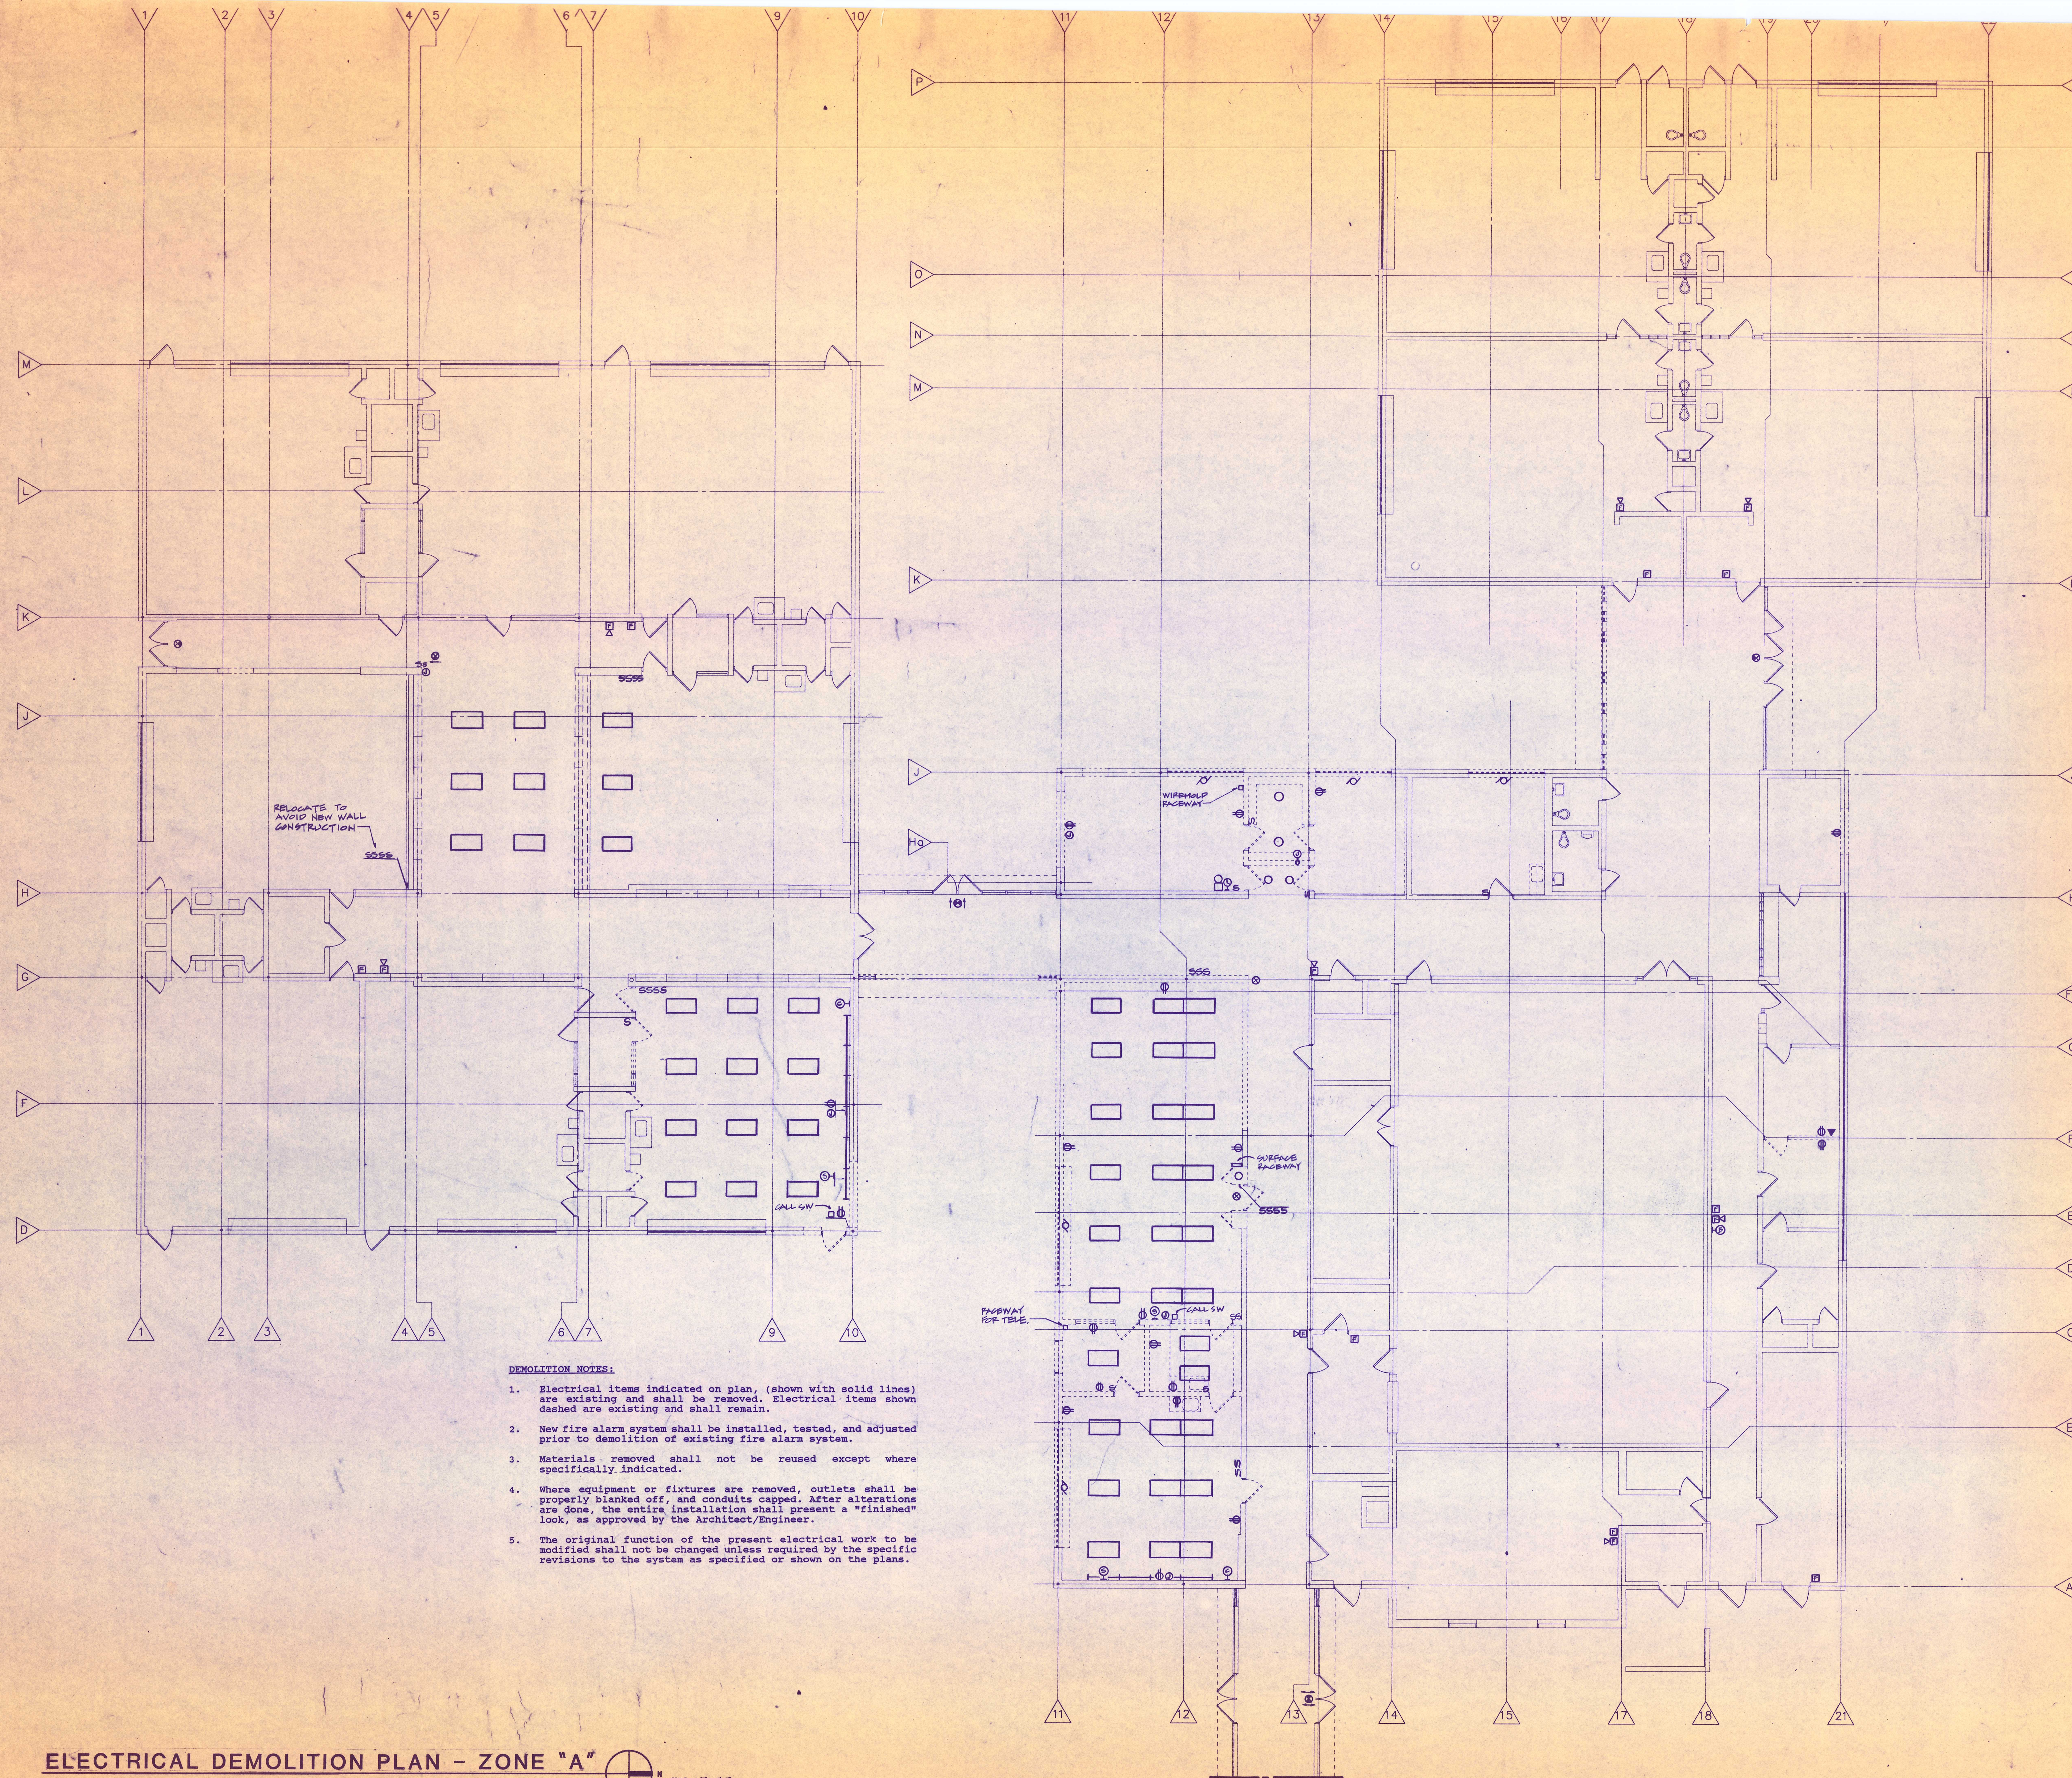

DEMOLITION NOTES:

1. Electrical items indicated on plan, (shown with solid lines) are existing and shall be removed. Electrical items shown dashed are existing and shall remain.
2. New fire alarm system shall be installed, tested, and adjusted prior to demolition of existing fire alarm system.
3. Materials removed shall not be reused except where specifically indicated.
4. Where equipment or fixtures are removed, outlets shall be properly blanked off, and conduits capped. After alterations are done, the entire installation shall present a "finished" look, as approved by the Architect/Engineer.
5. The original function of the present electrical work to be modified shall not be changed unless required by the specific revisions to the system as specified or shown on the plans.

ELECTRICAL DEMOLITION PLAN - ZONE "A"  SCALE: 1/8" = 1'-0"



TMP Associates, Inc.
Architects Engineers Planners
1191 W. Square Lake Rd.
P.O. Box 289
Bloomfield Hills, Mich.
48303-0289
(313) 338-4561

BERGGLIA ASSOCIATES, INC.
CREATIVE BUSINESS
(313) 358-1000 • FAX (313) 358-1001
24001 Northrup Ave. • Suite 101
Southfield, Michigan 48035
B.A.I. NO. 92-1801

project title
**Marshall
Elementary
Renovation**


sheet title
**Electrical
Demolition
Plan -
Zone "B"**

8-24-92 BIDS
8-17-92 95% OWNER REV.
date issued for

drawn BJG
checked JB
approved JB

job. no.
92014

sheet no.
E2.3

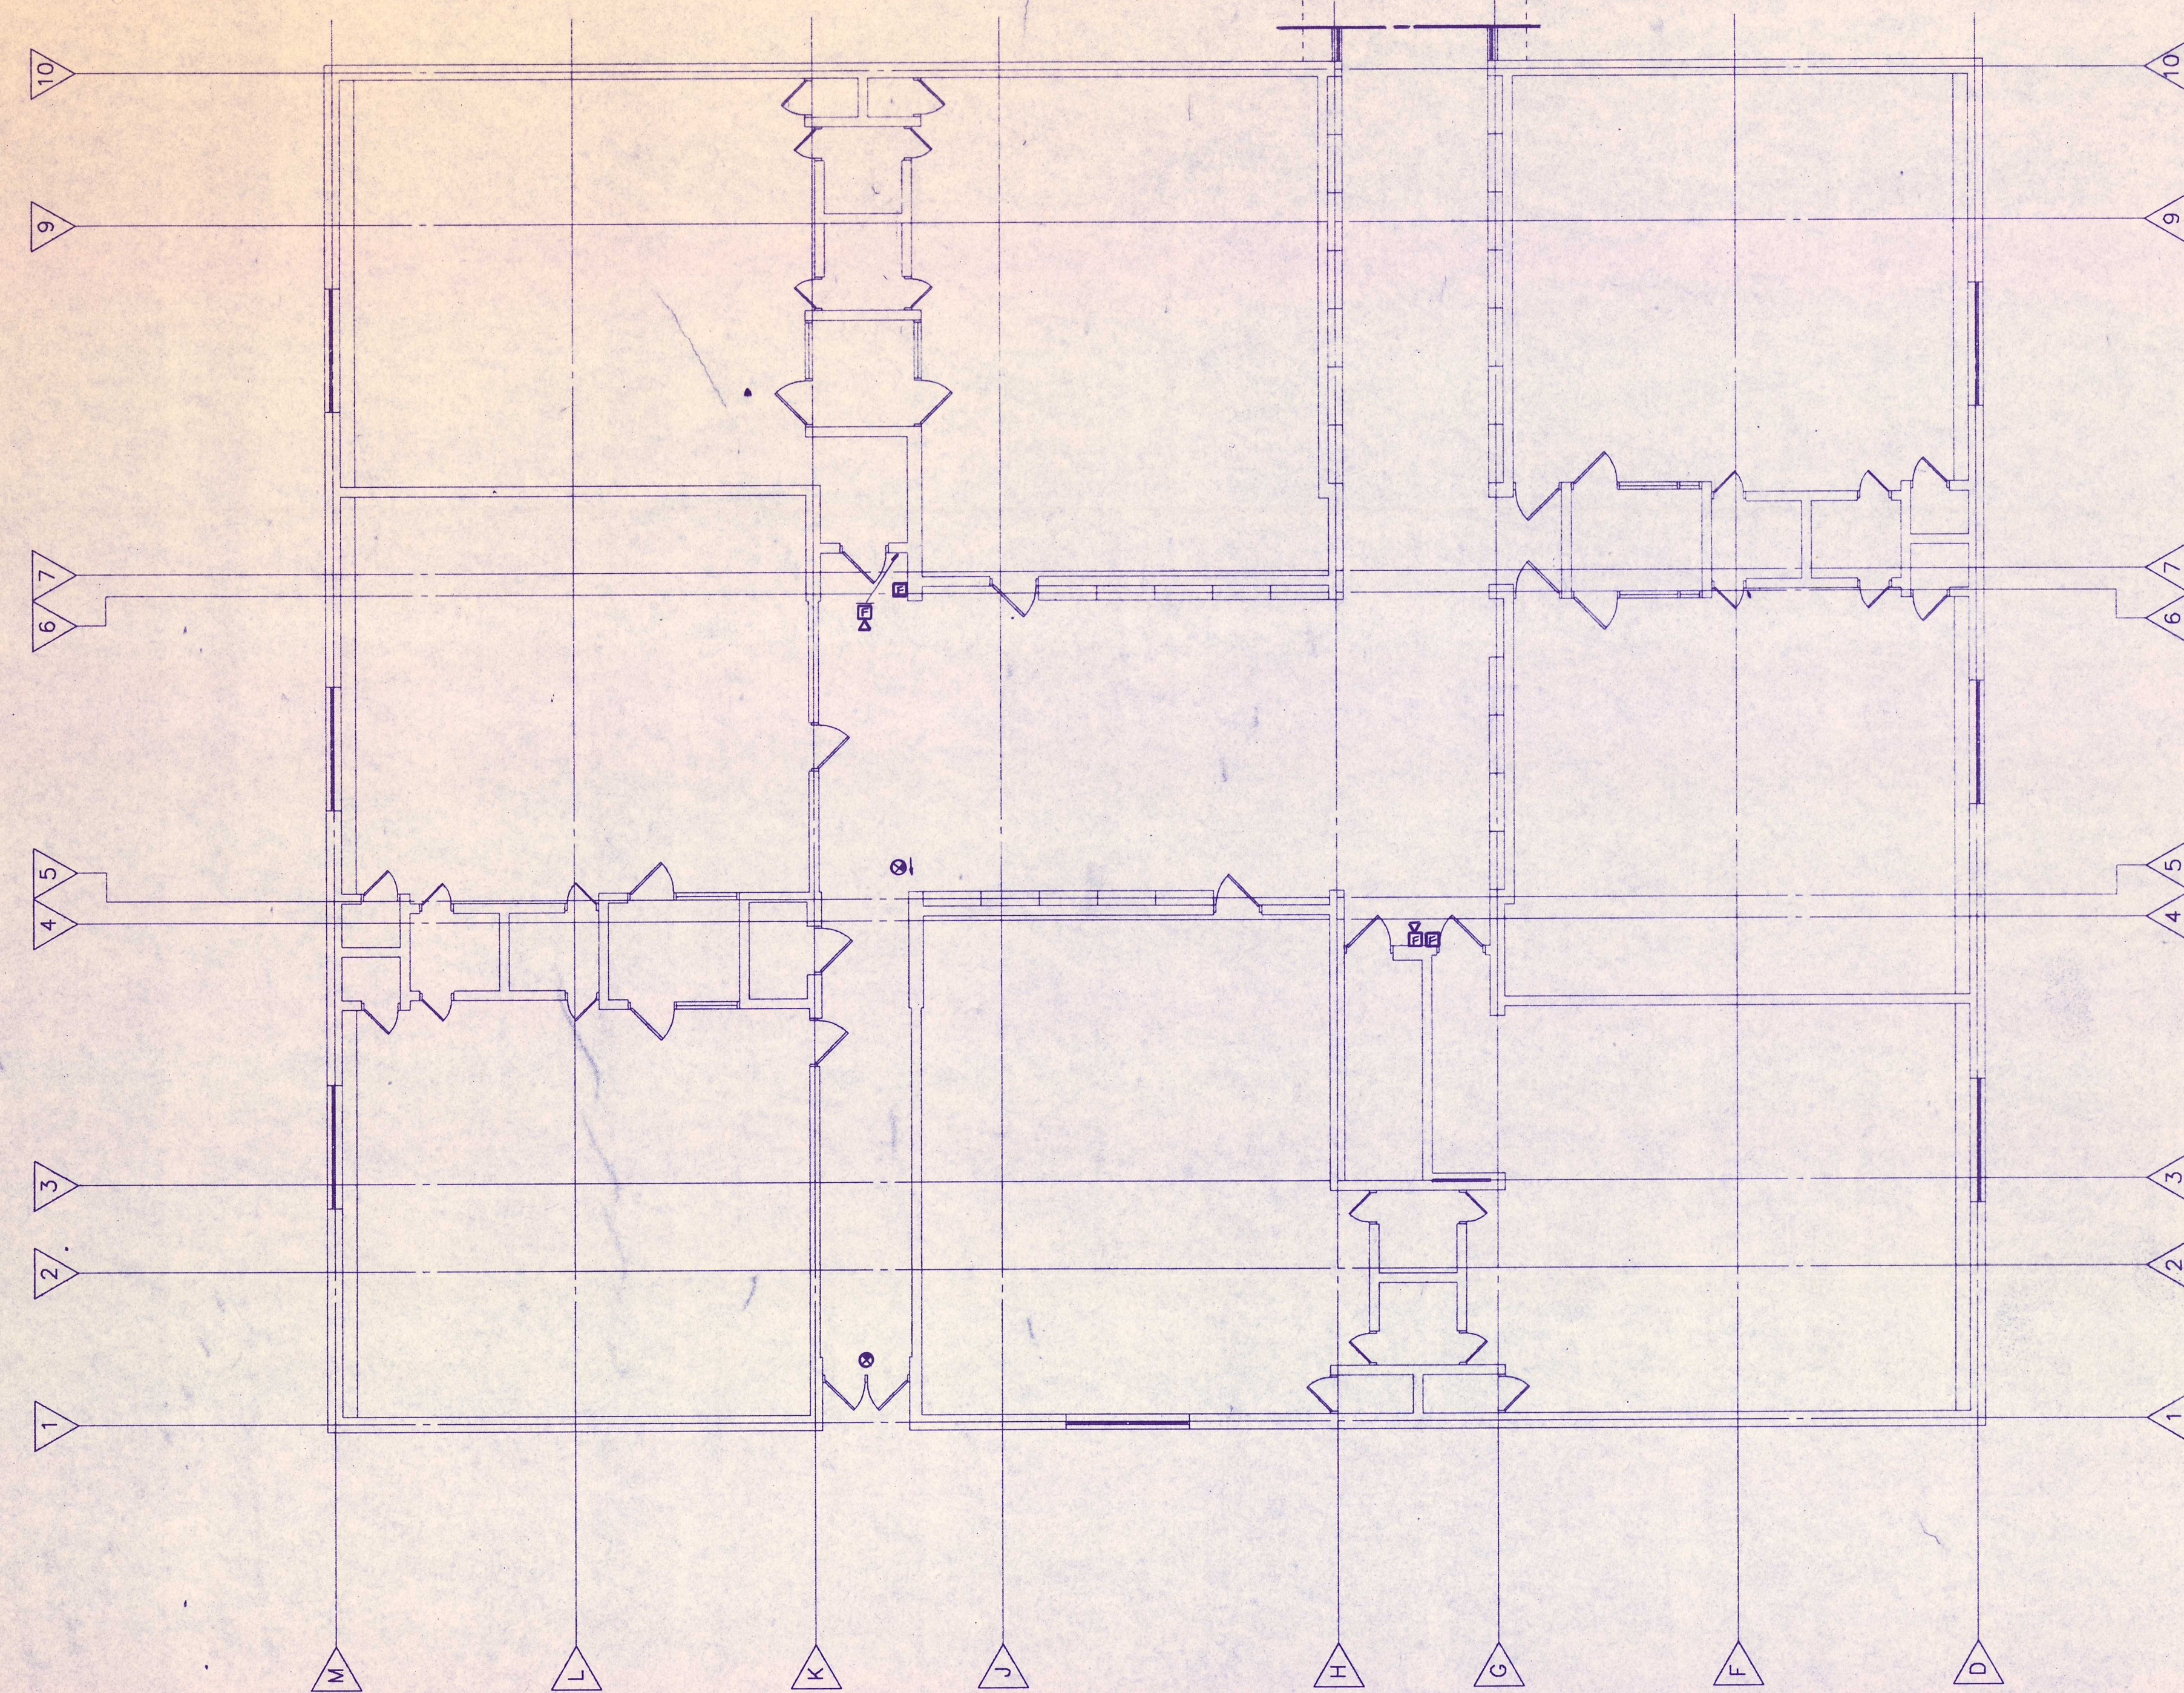

ELECTRICAL DEMOLITION PLAN - ZONE "B"  **SCALE: 1/8" = 1'-0"**

NOTE:
SEE SHEET E2.2 FOR
NOTES THIS SHEET.