

\\netr-file1\Users\cesar.silva_TETRI\Documents\13084-A-MCSD-260 K ST IT WAREHOUSE_cesar.silva.rvt



MERCED CITY SCHOOL DISTRICT

26TH STREET

MARS/ELO-P FACILITY

INCREMENT 01

DSA FILE NO.: 24 - 35

P.T.N.: 65771-142

DSA APPL. NO.: 02-123377

GENERAL

PROJECT ADDRESS: MARS/ELOP FACILITY
2600 K ST.
MERCED, CA. 95348

SITE INFORMATION

OWNER: MERCED CITY SCHOOL DISTRICT
ASMT: 0300220080000
GIS ACRES: 0.69
GIS SQDT: 30,000.00
APN: 030022008
PARCEL: 088
PARCEL NUMBER: 030-022-008

PROJECT DESCRIPTION

THIS PROJECT CONSISTS OF THE FOLLOWING:

INCREMENT NO.1:

SITE INFRASTRUCTURE INCREMENT.
SITE DEMOLITION REVIEW AND APPROVED BY THE CITY OF MERCED.
INCREMENT NO. 1 TO CONSIST OF BASIC SITE UTILITIES, GRADING, AND BUILDING PAD.

INCREMENT NO.2:

IMPROVEMENT INCREMENT TO INCLUDE MAIN BUILDING, STORAGE BUILDING, AND SITE IMPROVEMENTS.

CONSTRUCTION OF A NEW DISTRICT 2-STORY (10,500 SF) MULTI-USE FACILITY FOR STUDENTS AND ADULTS.
FACILITY TO INCLUDE:

- LOBBY
- CLASSROOM
- KITCHEN
- MULTI-USE SPACE
- STORAGE
- ELEVATOR
- OFFICE SPACE
- STANDARD SITE IMPROVEMENTS

CONSTRUCTION OF A NEW DISTRICT 1-STORY (1,500 SF) STORAGE BUILDING.
FACILITY TO INCLUDE:
- OPEN FLOOR SPACE FOR STORAGE

STATEMENT OF GENERAL CONFORMANCE

FOR ARCHITECTS/ENGINEERS WHO UTILIZE PLANS, INCLUDING BUT NOT LIMITED TO SHOP DRAWINGS, PREPARED BY OTHER LICENSED DESIGN PROFESSIONALS AND/OR CONSULTANTS.

APPLICATION NO.: 02-123377 FILE NO.: 24-35

THE DRAWINGS OR SHEETS LISTED ON THE COVER OR INDEX SHEET

HAVE BEEN PREPARED BY OTHER DESIGN PROFESSIONALS OR CONSULTANTS WHO ARE LICENSED AND/OR AUTHORIZED TO PREPARE SUCH DRAWINGS IN THIS STATE. IT HAS BEEN EXAMINED BY ME FOR:

1. DESIGN INTENT AND APPEARS TO MEET THE APPROPRIATE REQUIREMENTS OF TITLE 24, CALIFORNIA CODE OF REGULATIONS AND THE PROJECT SPECIFICATIONS PREPARED BY ME, AND

2. COORDINATION WITH MY PLANS AND SPECIFICATIONS AND IS ACCEPTABLE FOR INCORPORATION INTO THE CONSTRUCTION OF THIS PROJECT.

THE STATEMENT OF GENERAL CONFORMANCE "SHALL NOT BE CONSTRUED AS RELIEVING ME OF MY RIGHTS, DUTIES, AND RESPONSIBILITIES UNDER SECTIONS 17302 AND 81138 OF THE EDUCATION CODE AND SECTIONS 4-336, 4-341, AND 4-344" OF TITLE 24, PART I.

I CERTIFY THAT:

- ☒ ALL DRAWINGS OR SHEETS LISTED ON THE COVER OR INDEX
☐ THIS DRAWING OR PAGE

IS/ARE IN GENERAL CONFORMANCE AND HAVE BEEN COORDINATED WITH THE PROJECT PLANS AND SPECIFICATIONS

 09/03/2025
ARCHITECT'S SIGNATURE DATE
CHRIS NIKKEL
ARCHITECT/ PARTNER
TETER, INC.
C-35953 11-30-2025
LICENSE NUMBER EXPIRATION DATE

ARCHITECT'S STATEMENT

- A COPY TITLE 24 C.C.R. PARTS 1 THROUGH 6, PART 9 AND PART 12 SHALL BE KEPT ON THE JOB SITE AT ALL TIMES.
- CHANGES TO THE STRUCTURAL, ACCESSIBILITY OR FIRE AND LIFE-SAFETY PORTIONS OF THE APPROVED PLANS AND SPECIFICATIONS AFTER THE WORK HAS BEEN LET SHALL BE MADE BY A CONSTRUCTION CHANGE DOCUMENT (CCD) AS REQUIRED IN SECTION 4-338, PART I, CAC, AND SHALL BE SUBMITTED TO, AND APPROVED BY DSA PRIOR TO COMMENCEMENT OF THE WORK. CONSTRUCTION CHANGE DOCUMENTS SHALL BE PREPARED AND SUBMITTED TO DSA IN COMPLIANCE WITH DSA INTERPRETATION OF REGULATION IR A-6.
- ALL TESTS TO CONFORM TO THE REQUIREMENTS OF TITLE 24 SECTION 4-335, PART 1, AND APPROVED T & I SHEET.
- TESTS OF MATERIALS AND TESTING LABORATORY SHALL BE IN ACCORDANCE WITH TITLE 24 SECTION 4-335, PART I, AND THE DISTRICT SHALL EMPLOY AND PAY THE LABORATORY. COSTS OF RETEST MAY BE BACK CHARGED TO THE CONTRACTOR.
- DSA SHALL BE NOTIFIED AT THE START OF CONSTRUCTION AND PRIOR TO THE PLACEMENT OF THE CONCRETE PER TITLE 24 SECTION 4-331, PART I.
- A CLASS 1 INSPECTOR REQUIRED FOR THIS PROJECT SHALL BE EMPLOYED BY OWNER AND APPROVED BY ARCHITECT, STRUCTURAL ENGINEER, AND DSA. INSPECTOR SHALL BE IN ACCORDANCE WITH SECTION 4-333(c). THE DUTY OF THE INSPECTOR SHALL BE IN ACCORDANCE WITH TITLE 24 SECTION 4-342, PART I.
- SUPERVISION OF CONSTRUCTION BY DSA SHALL BE IN ACCORDANCE WITH TITLE 24 SECTION 4-334, PART 1.
- CONTRACTOR, INSPECTOR, ARCHITECT, AND ENGINEERS SHALL SUBMIT VERIFIED REPORTS (FORM SSS-6) IN ACCORDANCE WITH TITLE 24 SECTION 4-336, PART I.
- THE ARCHITECT AND THE STRUCTURAL ENGINEER SHALL PERFORM THEIR DUTIES IN ACCORDANCE WITH TITLE 24 SECTION 4-333(a) AND 4-341, PART I.
- THE CONTRACTOR SHALL PERFORM HIS DUTIES IN ACCORDANCE WITH TITLE 24 SECTION 4-343, PART I.
- THE INTENT OF THE DRAWINGS AND SPECIFICATIONS IS TO CONSTRUCT THE SCHOOL BUILDING IN ACCORDANCE WITH TITLE 24 C.C.R. SHOULD ANY CONDITIONS DEVELOP NOT COVERED BY THE CONTRACT DOCUMENTS WHEREIN THE FINISHED WORK WILL NOT COMPLY WITH SAID TITLE 24, C.C.R. A CHANGE ORDER DETAILING AND SPECIFYING THE REQUIRED WORK SHALL BE SUBMITTED TO AND APPROVED BY DSA BEFORE PROCEEDING WITH THE WORK.
- ADDENDA MUST BE SIGNED BY ARCHITECT AND APPROVED BY DSA.
- NO CHANGES OR REVISIONS SHALL BE MADE FOLLOWING WRITTEN APPROVAL WHICH AFFECTS ACCESS COMPLIANCE ITEMS UNLESS SUCH CHANGES OR REVISIONS ARE SUBMITTED TO THE DSA FOR APPROVAL.

- SUBSTITUTIONS AFFECTING DSA REGULATED ITEMS SHALL BE SUBMITTED AS A CONSTRUCTION CHANGE DOCUMENT OR ADDENDA, AND SHALL BE APPROVED BY DSA PRIOR TO FABRICATION AND INSTALLATION.
- CONSTRUCTION CHANGE DOCUMENTS MUST BE SIGNED BY THE FOLLOWING:
 - ARCHITECT OR ENGINEER OF RECORD
 - STRUCTURAL ENGINEER (WHEN APPLICABLE)
 - DELEGATED PROFESSIONAL ENGINEER
- MATERIALS AND THEIR INSTALLATION SHALL COMPLY WITH APPLICABLE CODES, STANDARDS AND MANUFACTURER'S RECOMMENDATIONS.
- GRADING PLANS, DRAINAGE IMPROVEMENTS, ROAD AND ACCESS REQUIREMENTS AND ENVIRONMENTAL HEALTH CONSIDERATIONS SHALL COMPLY WITH ALL LOCAL ORDINANCES.
- DSA IS NOT SUBJECT TO ARBITRATION.
- A DSA ACCEPTED TESTING LABORATORY DIRECTLY EMPLOYED BY THE DISTRICT (OWNER) SHALL CONDUCT ALL THE REQUIRED TESTS AND INSPECTIONS FOR THE PROJECT.
- THE CALIFORNIA ENERGY CODE SECTION 10-103 REQUIRES ACCEPTANCE TESTING ON ALL NEWLY INSTALLED LIGHTING CONTROLS, MECHANICAL SYSTEMS, ENVELOPES, AND PROCESS EQUIPMENT AFTER INSTALLATION AND BEFORE PROJECT COMPLETION. AN ACCEPTANCE TEST IS A FUNCTIONAL PERFORMANCE TEST TO HELP ENSURE THAT NEWLY INSTALLED EQUIPMENT IS OPERATING AND IN COMPLIANCE WITH THE ENERGY CODE.
- LIGHTING CONTROLS ACCEPTANCE TESTS MUST BE PERFORMED BY A CERTIFIED MECHANICAL ATT FOR PROJECTS SUBMITTED ON OR AFTER OCTOBER 1, 2021.
- A LISTING OF CERTIFIED ATT'S CAN BE FOUND AT [HTTPS://WWW.ENERGY.CA.GOV/PROGRAMS-AND-TOPICS/PROGRAMS/ACCEPTANCE-TEST-TECHNICIAN-CERTIFICATION-PROVIDER-PROGRAM/ACCEPTANCE](https://www.energy.ca.gov/programs-and-topics/programs/acceptance-test-technician-certification-provider-program/acceptance)
- THE ACCEPTANCE TESTING PROCEDURES MUST BE REPEATED, AND DEFICIENCIES MUST BE CORRECTED BY THE BUILDER OR INSTALLING CONTRACTOR UNTIL THE CONSTRUCTION/INSTALLATION OF THE SPECIFIED SYSTEMS CONFORM AND PASS THE REQUIRED ACCEPTANCE CRITERIA.
- PROJECT INSPECTORS WILL BE COLLECTING THE FORMS TO CONFIRM THAT THE REQUIRED ACCEPTANCE TESTS HAVE BEEN COMPLETED.
- ARCHITECT OF RECORD (AOR) SHALL CONTACT THE LOCAL FIRE DEPARTMENT AND/OR EMERGENCY COMMUNICATIONS AUTHORITY TO OBTAIN DESIGN AND EQUIPMENT SPECIFICATIONS, AND TESTING AND ACCEPTANCE CRITERIA. IT IS THE RESPONSIBILITY OF THE DESIGN PROFESSIONAL/AOR TO SUBMIT PLANS AND REQUESTED DOCUMENTATIONS, AND APPLICABLE FEES, TO THE LOCAL AUTHORITY HAVING JURISDICTION FOR REVIEW AND APPROVAL. UPON COMPLETION, COPIES OF THE APPROVED, EQUIPMENT DATA SHEETS, AND PROOF OF TESTING AND ACCEPTANCE DOCUMENTATION SHALL BE PROVIDED TO THE SCHOOL DISTRICT. THE PROJECT INSPECTORS SHALL VERIFY THAT DOCUMENTATION IS PROVIDED TO THE SCHOOL DISTRICTS.

OWNER

MERCED CITY SCHOOL DISTRICT

444 W. 23RD. ST.
MERCED, CA, 95340
(209) 385-6343

CONTACT: BRAYN BEHN

EMAIL: BBehn@mcsd.k12.ca.us

PROJECT ARCHITECT

TETER, INC.

7535 N. PALM AVE., SUITE 201
FRESNO, CA 93711
(559) 437-0887

CONTACT: CHRIS NIKKEL

E-MAIL: chris.nikkel@teterae.com

BUILDING AOR

YC+D ARCHITECTURE

712 BANCROFT ROAD #297
WALNUT CREEK, CA 94589
(925) 979-5178

CONTACT: DARA DOURAGHI

E-MAIL: dara@ycpld.com

CIVIL ENGINEER

BLAIR, CHURCH & FLYNN

451 CLOVIS AVENUE, SUITE 200
CLOVIS, CA. 93612
(559) 326-1400

CONTACT: ZACHARY HOCKETT

EMAIL: zhockett@bcf-engr.com

ELECTRICAL ENGINEER

TETER, LLP

7535 N. PALM AVE., SUITE 201
FRESNO, CA. 93711
(559) 437-0887

CONTACT: EVAN BASTIAN

EMAIL: evan.bastian@teterae.com

PROJECT DIRECTORY

NON-SEPERATED OCCUPANCY: A3 (THE MOST STRINGENT) TO ELIMINATE THE OTHERWISE FIRE SEPERATION REQUIREMENT BETWEEN B AND A, E OCCUPANCIES PER TABLE 508.4

RISK CATEGORY: III

ACTUAL AREA AND HEIGHT: 1075 S.F. AND 24'-5 1/2"

OCCUPANCY TYPE: A3-COMMUNITY HALL, E-EDUCATION, B-CIVIC ADMIN.

CONSTRUCTION TYPE: V-B


AUTOMATIC SPRINKLERS THROUGHOUT: YES

ALLOWABLE AREA AND HEIGHT (C.B.C. 2022 TABLES 504.3, 504.4, 506.2 AND SECTION 506.3)
NUMBER OF STORIES: 2 FOR SPRINKLERED MULTI STORY (W/O AREA INCREASE)
BUILDING HEIGHT: 60' FOR SPRINKLERED MULTI STORY (W/O AREA INCREASE)
MAX. BLDG. AREA (S1): 18,000 S.F. FOR SPRINKLERED MULTI STORY (W/O HEIGHT INCREASE)

REFER TO SHEET G100 SERIES FOR COMPLETE CODE ANALYSIS BY BUILDING SERIES AND SHEET S001 FOR STRUCTURAL PROJECT DESIGN CRITERIA.

- DESIGN FOR ENERGY COMPLIANCE IN THE WORST-CASE ORIENTATION IN CLIMATE ZONES 14, 15, AND 16. THEREFORE CAN BE PLACED ON ANY CALIFORNIA CLIMATE ZONE.
- NOT APPROVED FOR USE AS SCIENCE CLASSROOM/LABORATORIES WITH SPECIAL HAZARDS OR PROCESSES OR VOCATIONAL USES.
- NOT ELIGIBLE FOR STOCKPILE APPLICATION OR RELOCATION.
- GEO-HAZARD REPORT REQUIRED FOR EACH SITE APPLICATION PER DSA PL 07-02 3.1.5.
- ACOUSTICAL CONTROL: WHEN PRE-CHECK BUILDING IS SITE ADAPTED, THE BUILDING AND SITE FEATURES NEED TO COMPLY WITH THE CALGREEN CODE, SECTION 5.507.4 FOR THE SITE LOCATION. WHEN A PC BUILDING IS IN PLACE ADJACENT TO ANOTHER PC BUILDING, THE ADJOINING WALL SECTION FOR INTERIOR SOUND TRANSMISSION MUST MEET THE MINIMUM REQUIREMENT OF AN STC RATING OF 40 (PER 2022 CALGREEN CODE, SECTION 5.507.4.3).
- THE DAYLIGHT AREAS COMPLY WITH THE MANDATORY REQUIREMENTS OF ENERGY CODE SECTION 130.10(1)
- WHEN THE PRE-CHECK BUILDING IS SITE ADAPTED, THE BUILDING SHALL HAVE A SOLAR ZONE TOTAL AREA NO LESS THAN 15 PERCENT OF THE PC'S TOTAL ROOF AREA.
- ANY CHANGES TO THE BUILDING FIRE SPRINKLER DESIGN WILL REQUIRE A SEPERATE DSA APPLICATION NUMBER
- DESIGNED FOR PLACEMENT IN ALL FIRE HAZARD SEVERITY ZONES PER CBC CHAPTER 7A.
- ALL CONSTRUCTION AND DEMOLITION SHALL BE IN ACCORDANCE WITH CHAPTER 33 OF THE CBC AND CFC, AND THE WRITTEN SITE FIRE SAFETY PLAN.

BUILDING DATA

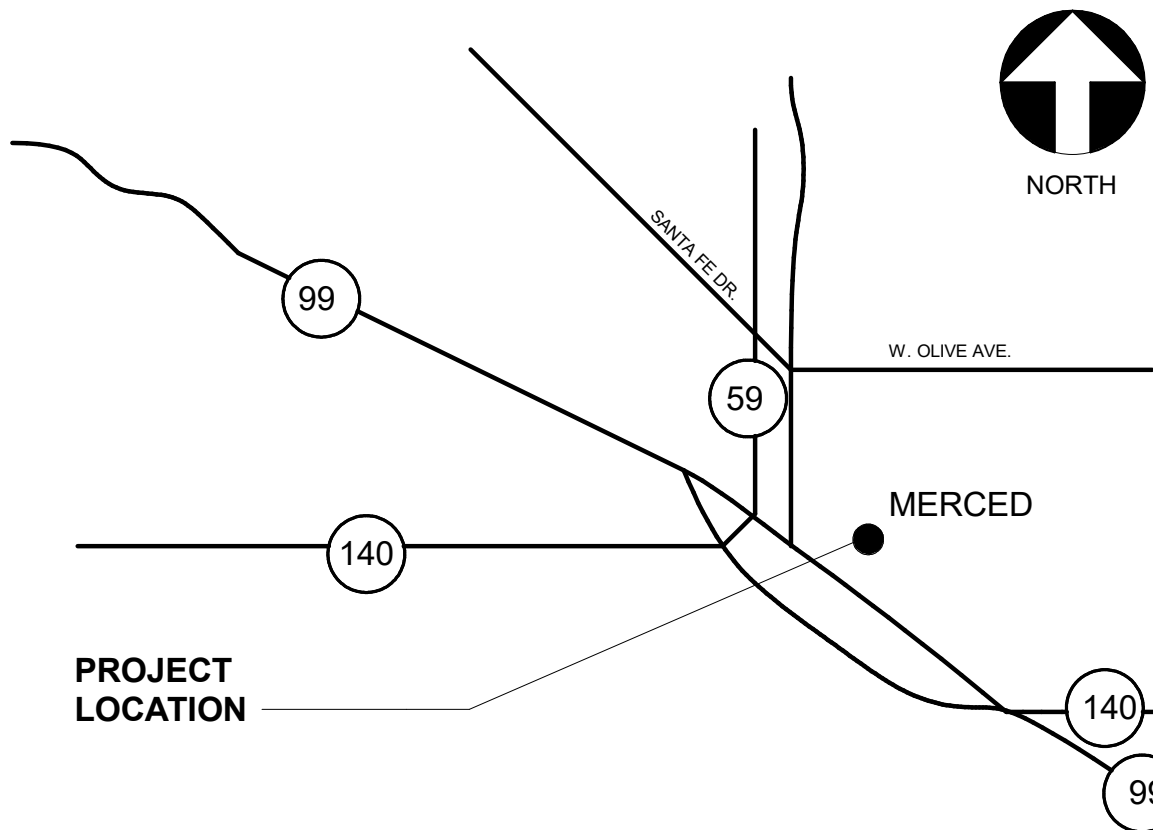

AREA MAP



VICINITY MAP

ENFORCING AGENCY:

DIVISION OF THE STATE ARCHITECT / SACRAMENTO REGIONAL OFFICE.

FLOOD ZONE:

- FLOOD ZONE DESIGNATION: ZONE AO
- FLOOD INSURANCE RATE MAP (FIRM) PANEL DESIGNATION: 408 OF 1225
- EFFECTIVE DATE OF FIRM: DECEMBER 2, 2008
- DESIGN FLOOR ELEVATION (DFE): 173.12
- APPLICABLE COMMUNITY ORDINANCE SECTION: CITY OF MERCED, 060188

GENERAL INFORMATION


NONE

DEFERRED SUBMITTALS


IDENTIFICATION STAMP
DIV. OF THE STATE ARCHITECT
APP: 02-123377 INC: 01
REVIEWED FOR
SS ☒ FLS ☒ ACS ☒
DATE: 11/18/2025

Teter, Inc. expressly reserves its common law copyright and other property rights in these plans. This document, the ideas and designs incorporated herein, as an instrument of professional service, is not to be used for any other project without prior written authorization.

MARK	DATE	DESCRIPTION
	09/03/2025	INC. 02 DSA BACKCHECK

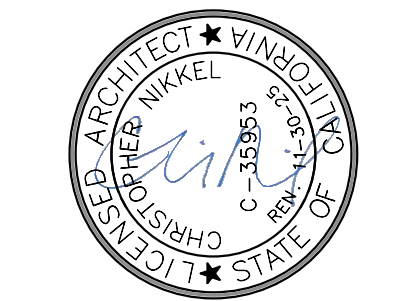

TETER, INC.
FRESNO HEADQUARTERS
VISALIA | BAKERSFIELD | MODESTO | SAN LUIS OBISPO
ARCHITECTS ENGINEERS CONNECTED

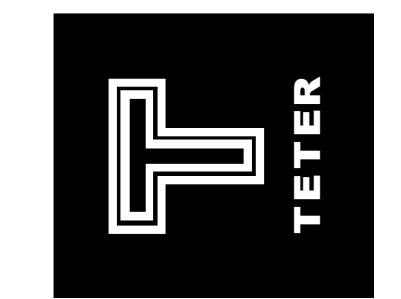

26TH STREET MARSELO-P FACILITY
MERCED CITY SCHOOL DISTRICT
2600 K STREET
MERCED, CA 95348
DRAWING TITLE
COVER SHEET

 
PROJECT NO.

24-13084.00

DRAWING

G000-01

PLOT DATE: 8/26/2025 9:18:37 AM



GENERAL	
G000-01	COVER SHEET
G001-01	SHEET INDEX
2	
CIVIL	
C501-01	GRADING PLAN AND DRAINAGE PLAN
C601-01	UTILITY PLAN
X106-01	DETAILS
3	
ARCHITECTURAL	
A000-01	LEGENDS AND ABBREVIATIONS
A100-01	OVERALL PROPOSED SITE PLAN
2	
ELECTRICAL	
E100-01	DEMOLITION ELECTRICAL SITE PLAN
E800-01	ELECTRICAL NOTES & LEGEND
2	
TOTAL PAGES: 9	

26TH STREET MARS/LO-P FACILITY
MERCED CITY SCHOOL DISTRICT

2600 K STREET
MERCED, CA 95348

DRAWING TITLE


SHEET INDEX

PROJECT NO.

24-13084.00

DRAWING

G001-01

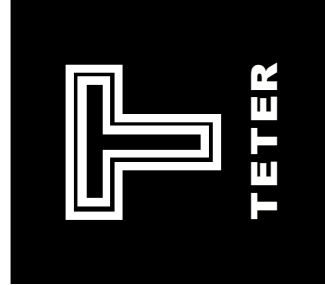

TETER, INC.

FRESNO HEADQUARTERS

VISALIA | BAKERSFIELD | MODESTO | SAN LUIS OBISPO

ARCHITECTS ENGINEERS CONNECTED



Teter, Inc. expressly reserves its common law copyright and other property rights in these plans. This document, the ideas and designs incorporated herein, as an instrument of professional service, is not to be used for any other project without prior written authorization.	
MARK	DATE
	09/03/2025
INC. 02 DSA BACKCHECK	

IDENTIFICATION STAMP

DIV. OF THE STATE ARCHITECT

APP: 02-123377 INC: 01

REVIEWED FOR

SS ☒ FLS ☒ ACS ☒

DATE: 11/18/2025



0 5 10 20
SCALE IN FEET




**Know what's below.
Call before you dig.**

Blair,
Church
& Flynn

451 Clovis Avenue, Suite 200
Clovis, California 93612
Tel (559) 326-1400
Fax (559) 326-1500

C501-01

Drawing: P:\224\224-0395\Site\production\drawings\224395_gr01.dwg; Layout: 1
Plot by: avargas Aug 25, 2025 - 3:12pm

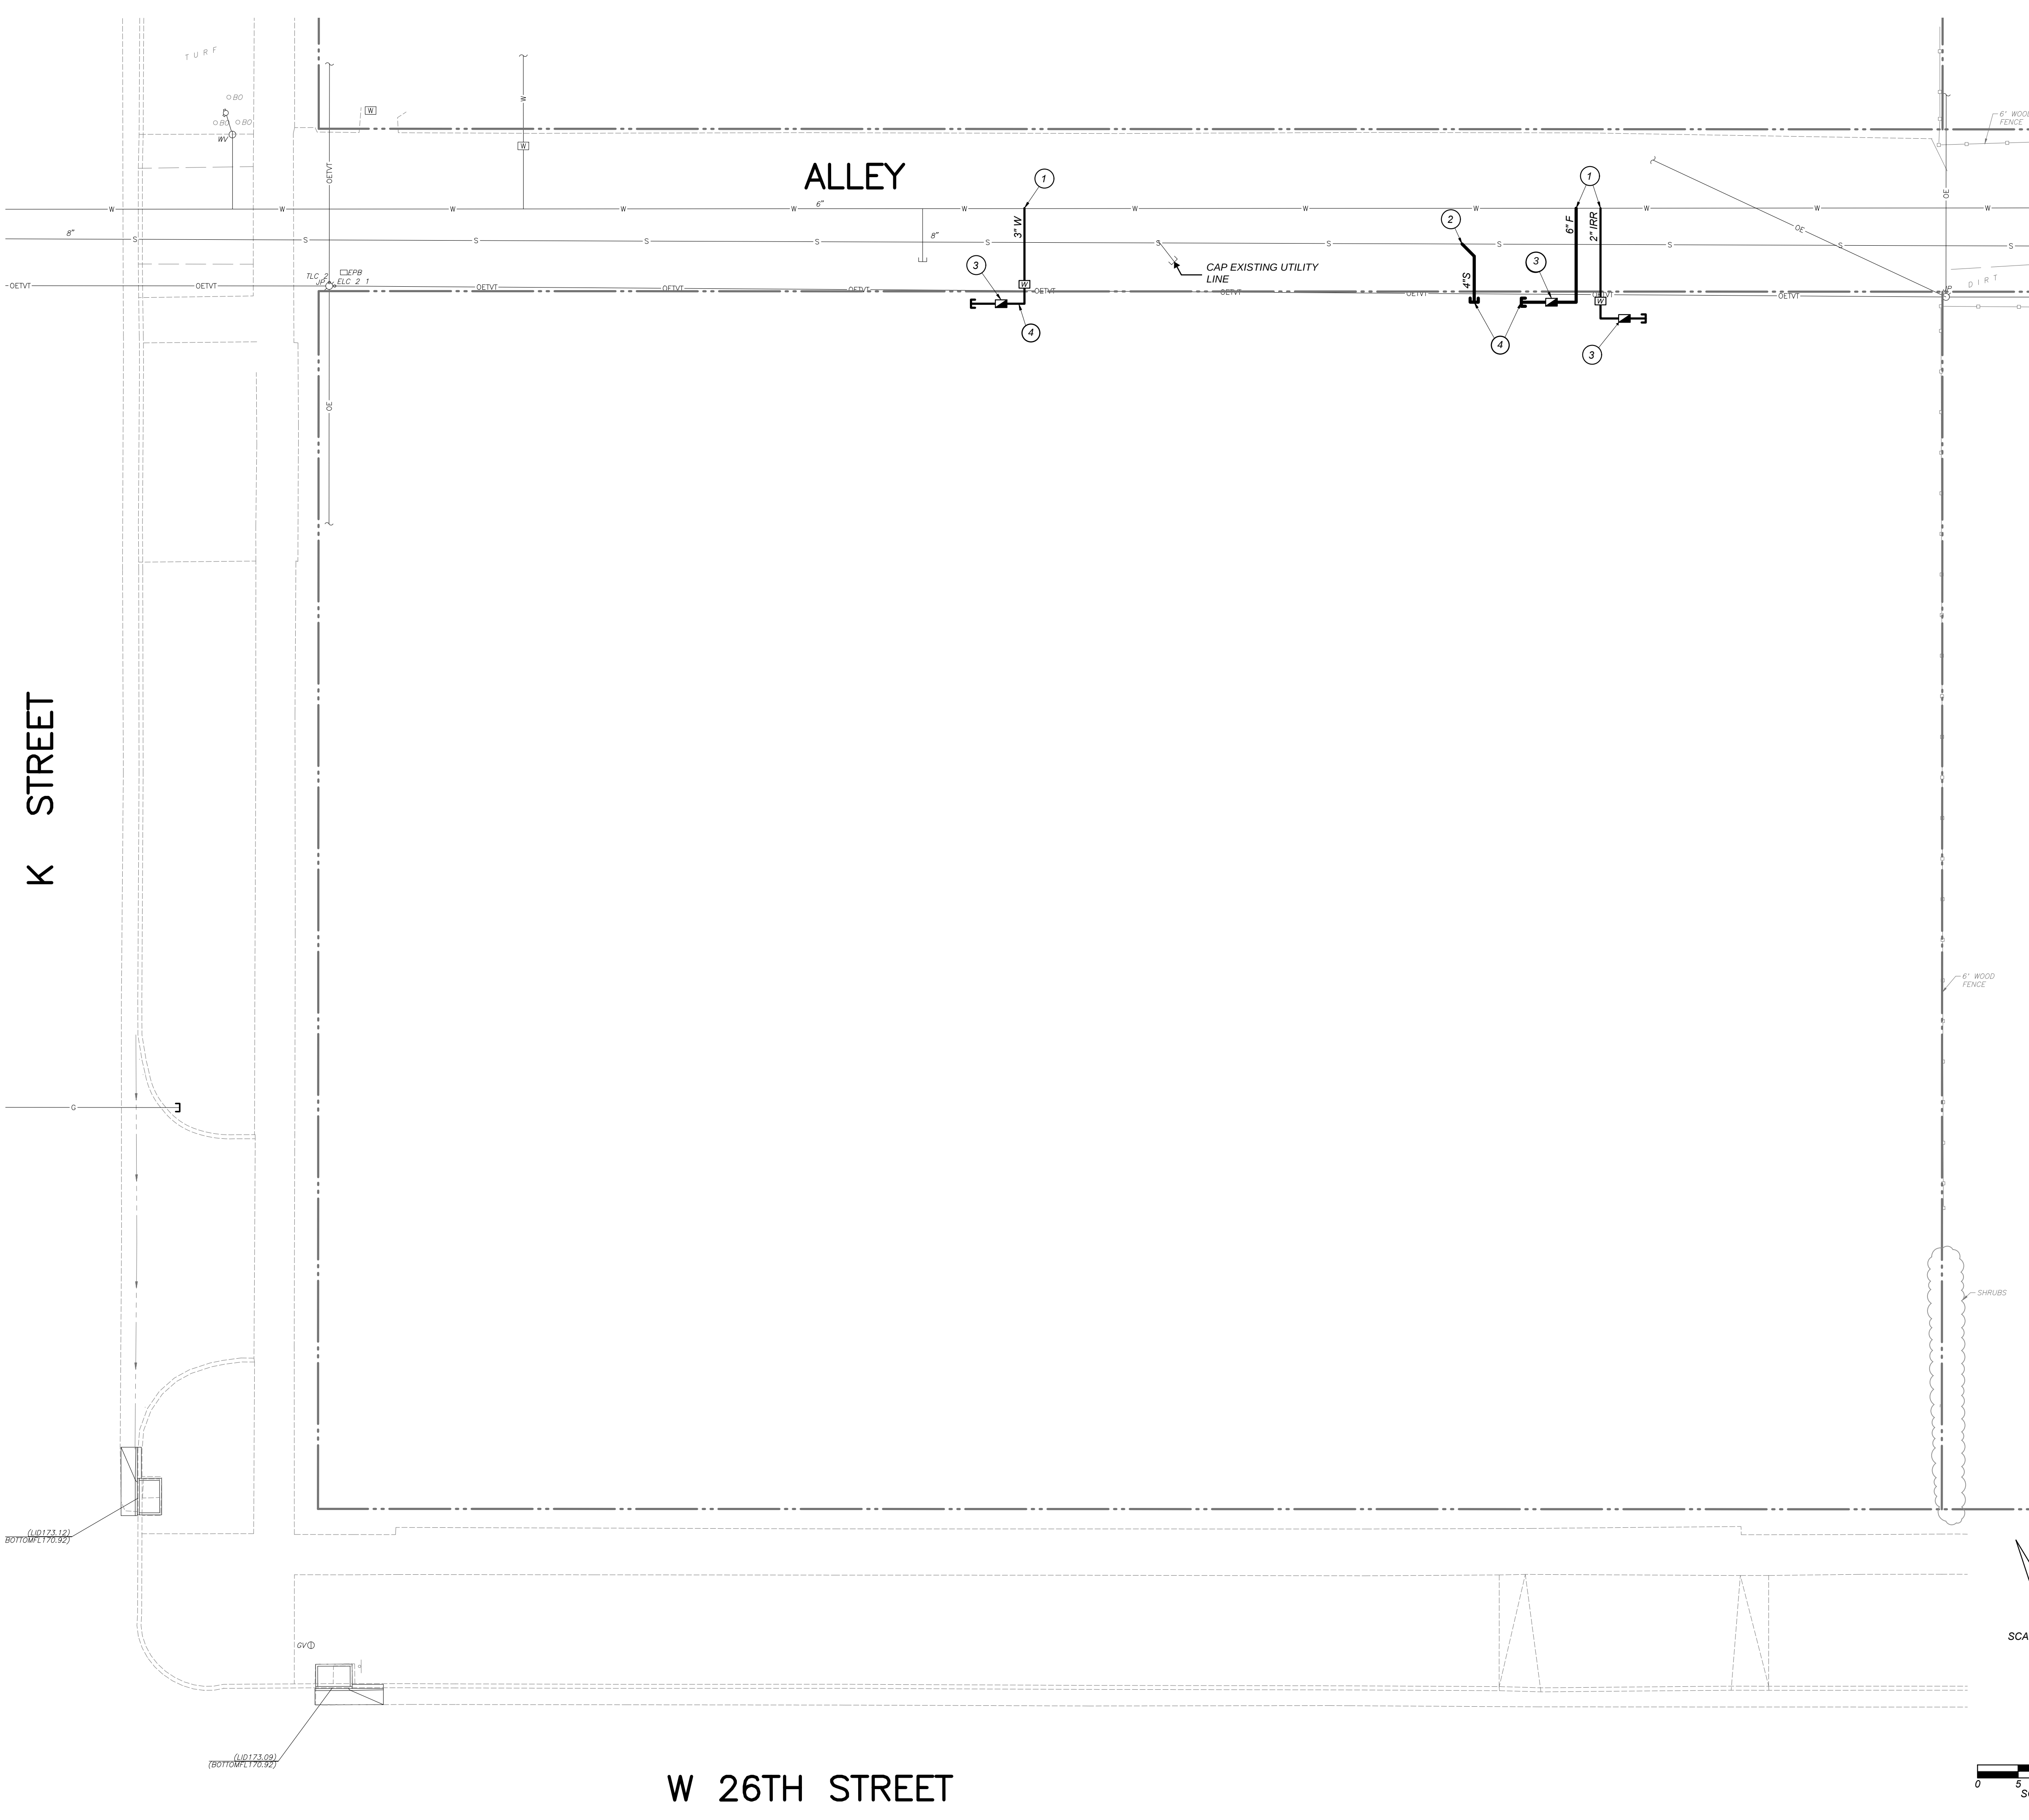

UTILITY LEGEND:

- S** SEWER MAIN, SIZE AS NOTED ON PLANS. PIPE BEDDING AND BACKFILL PER [B/X106-01]
- W** WATER MAIN, SIZE AS NOTED ON PLANS. MIN. 30" COVER. THRUST BLOCKS PER [A/X106-01]. PIPE BEDDING AND BACKFILL PER [B/X106-01]
- F** DUCTILE IRON FIRE MAIN, SIZE AS NOTED ON PLANS. MIN. 42" COVER. THRUST BLOCKS PER [A/X106-01]. PIPE BEDDING AND BACKFILL PER [B/X106-01]
- WATER METER PER CITY OF MERCED CITY STD. W-4
- CAP END OF UTILITY LINE.
- BACKFLOW PREVENTER
- FLOWLINE SLOPE AND DIRECTION OF FLOW
- CONNECTION TO THE EXISTING SERVICE MAIN SHALL BE COMPLETED BY THE CITY OF MERCED PER MERCED STD W-17
- CONNECT TO EXISTING SEWER MAIN PER CITY OF MERCED STD. S-7
- ZURN MODEL 350 DA DOUBLE CHECK BACKFLOW PREVENTER PER CITY OF MERCED STD. W-8 AND W-17, SEE [D/X106-01]
- COORDINATE SERVICE CONNECTION LOCATIONS WITH INCREMENT 2 DESIGN

GENERAL SITE UTILITY NOTES:

- AS FIRST ORDER OF WORK, CONTRACTOR SHALL POTHOLE EXISTING UTILITIES AND NOTIFY ENGINEER IMMEDIATELY OF LOCATIONS, SIZE AND DEPTH.
- THE CONTRACTOR SHALL FIELD VERIFY THE EXACT LOCATION, SIZE, DEPTH, AND TYPE OF ALL EXISTING UTILITIES AND INTERFERENCES SITUATED ALONG THE ROUTE OF THE PROPOSED CONSTRUCTION PRIOR TO COMMENCEMENT OF EXCAVATION, FABRICATION, AND INSTALLATION. THE CONTRACTOR SHALL CONSTRUCT ALL IMPROVEMENTS IN SUCH A MANNER AS WILL PROTECT ALL EXISTING UNDERGROUND UTILITIES AND, IN THE EVENT OF ANY CONFLICTS, SHALL NOTIFY THE ENGINEER BEFORE PROCEEDING.
- COORDINATE EXACT POINTS OF CONNECTION TO BUILDING PLUMBING AND NOTIFY THE ENGINEER OF ANY CONFLICT SO THAT ADJUSTMENTS CAN BE MADE IF NEEDED.
- BACKFILL UTILITY TRENCHES PER DETAIL [B/X106-01]
- INSTALLATION, TYPE, AND MANUFACTURER'S MODELS OF DOMESTIC WATER METERS, DRAIN INLETS/OUTLETS AND OTHER APPURTENANCES OF SITE UTILITY SYSTEMS SHALL BE DONE IN STRICT ACCORDANCE WITH GOVERNING AUTHORITY REQUIREMENTS.
- LAYOUT OF MATERIALS, EQUIPMENT AND SYSTEMS IS GENERALLY DIAGRAMMATIC UNLESS SPECIFICALLY DIMENSIONED. SOME WORK MAY BE SHOWN OFFSET FOR CLARITY. THE ACTUAL LOCATIONS OF ALL MATERIALS, PIPING, FIXTURES, EQUIPMENT, SUPPORTS, ETC., SHALL BE CAREFULLY PLANNED PRIOR TO INSTALLATION OF ANY WORK TO AVOID ALL INTERFERENCES WITH EACH OTHER OR WITH STRUCTURAL, ELECTRICAL, PLUMBING AND MECHANICAL, ARCHITECTURAL OR ANY OTHER ELEMENTS. ALL CONFLICTS SHALL BE CALLED TO THE ATTENTION OF THE ARCHITECT AND THE ENGINEER PRIOR TO THE INSTALLATION OF ANY WORK OR THE ORDERING OF ANY EQUIPMENT.
- ANY INSPECTION TO BE MADE BY THE AUTHORITY HAVING JURISDICTION SHALL REQUIRE A MINIMUM OF 24 HOUR NOTICE.
- PURITY TESTS ARE REQUIRED ON ALL WATER SYSTEM INSTALLATIONS. CONTRACTOR TO COORDINATE WITH THE AUTHORITY HAVING JURISDICTION.
- IF THE TOP OF THE STEM OF ANY WATER GATE VALVE IS DEEPER THAN 4' BELOW FINISHED PAVEMENT GRADE, THE CONTRACTOR SHALL INSTALL A STEM EXTENSION SO THAT THE TOP OF THE STEM, WITH EXTENSION, SHALL BE NO DEEPER THAN 4' NOR SHALLOWER THAN 2' FROM FINISHED GRADE.

SCALE: 1"=10'

SCALE IN FEET



Know what's below.
Call before you dig.

Blair Church & Flynn
CONSULTING ENGINEERS

461 Davis Avenue, Suite 200
Clovis, California 93612
Tel (559) 326-1400
Fax (559) 326-1500


IDENTIFICATION STAMP
DIV. OF THE STATE ARCHITECT
APP: 02-123377 INC: 01
REVIEWED FOR
SS ☒ FLS ☒ ACS ☒
DATE: 11/18/2025

Teter, LLP expressly reserves its common law copyright and other property rights in these plans. Any reproduction, use, or modification of these plans without the written consent of Teter, LLP is prohibited. This instrument is not to be used in whole or in part, for any other project without prior written authorization.

MARK	DATE	DESCRIPTION
	09/03/2025	INC. 02 DSA BACKCHECK



TETER, INC.
FRESNO HEADQUARTERS
VISALIA | BAKERSFIELD | MODESTO | SAN LUIS OBISPO
ARCHITECTS ENGINEERS CONNECTED

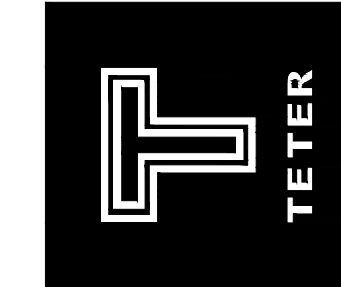

26TH STREET MARSVELO-P FACILITY
MERCED CITY SCHOOL DISTRICT
2600 K STREET
MERCED, CA 95348
DRAWING TITLE
UTILITY PLAN

PROJECT NO.
24-13084.00

DRAWING
C601-01


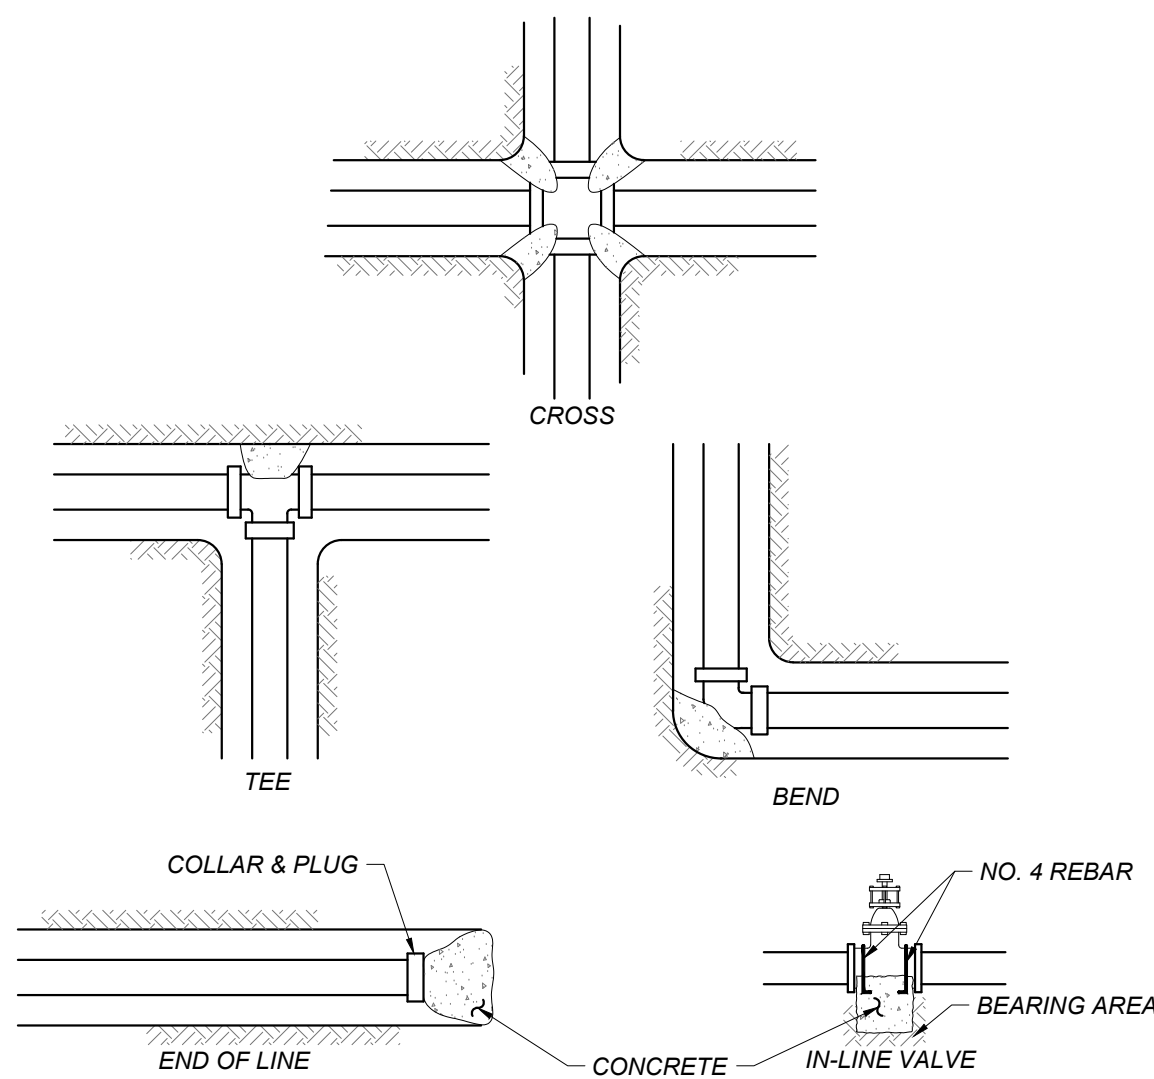


Table Of Bearing Areas Required (In Square Feet)*				
Pipe Diameter	4" Or Smaller	6"	8"	10"
Cross, Tee, 90° Bend, Plug, Hydrant, Valve	6.3	13.2	22.7	34.2
45° Bend	3.4	7.1	12.3	18.5
22 1/2° Bend	1.7	3.6	9.4	13.3
11 1/4° Bend	0.9	1.8	4.7	6.7

* TABLE CALCULATED BASED ON NFPA 24, CURRENT EDITION TABLE A.10.8.2(b), WITH 250 PSI WATER PRESSURE AND 1500 PSF SOIL BEARING PRESSURE.


A CONCRETE THRUST BLOCKS

NOT TO SCALE

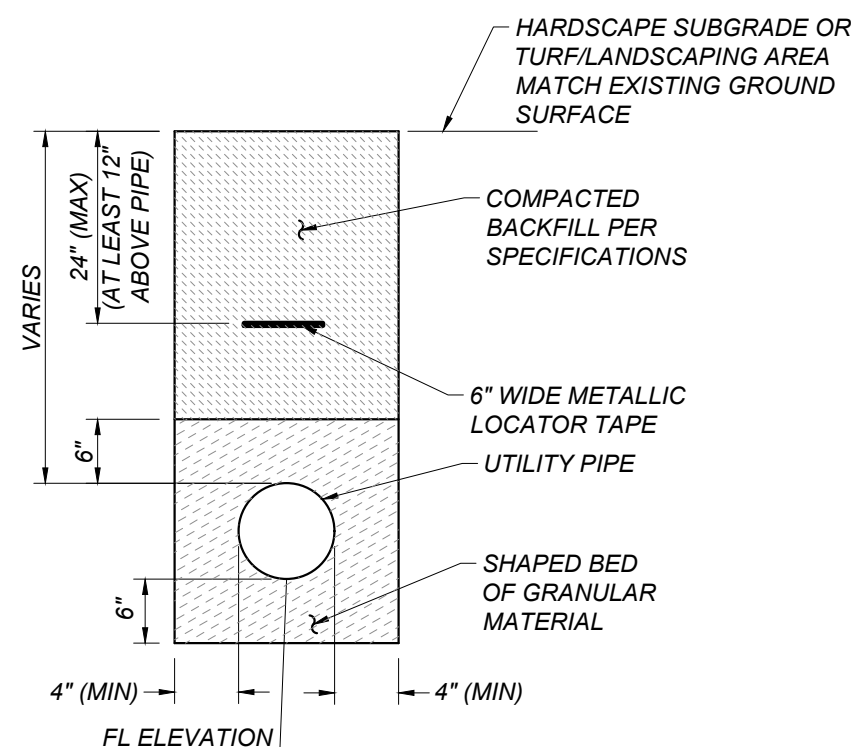


B TRENCH DETAIL FOR UTILITY LINES

NOT TO SCALE

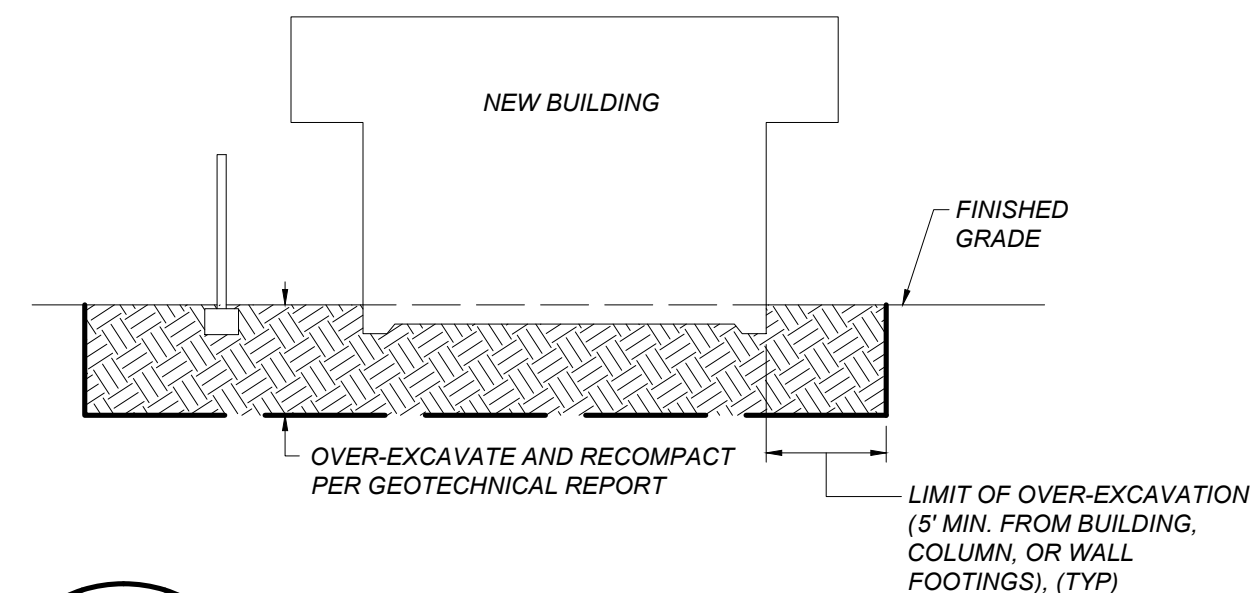

C OVER-EXCAVATION

NOT TO SCALE

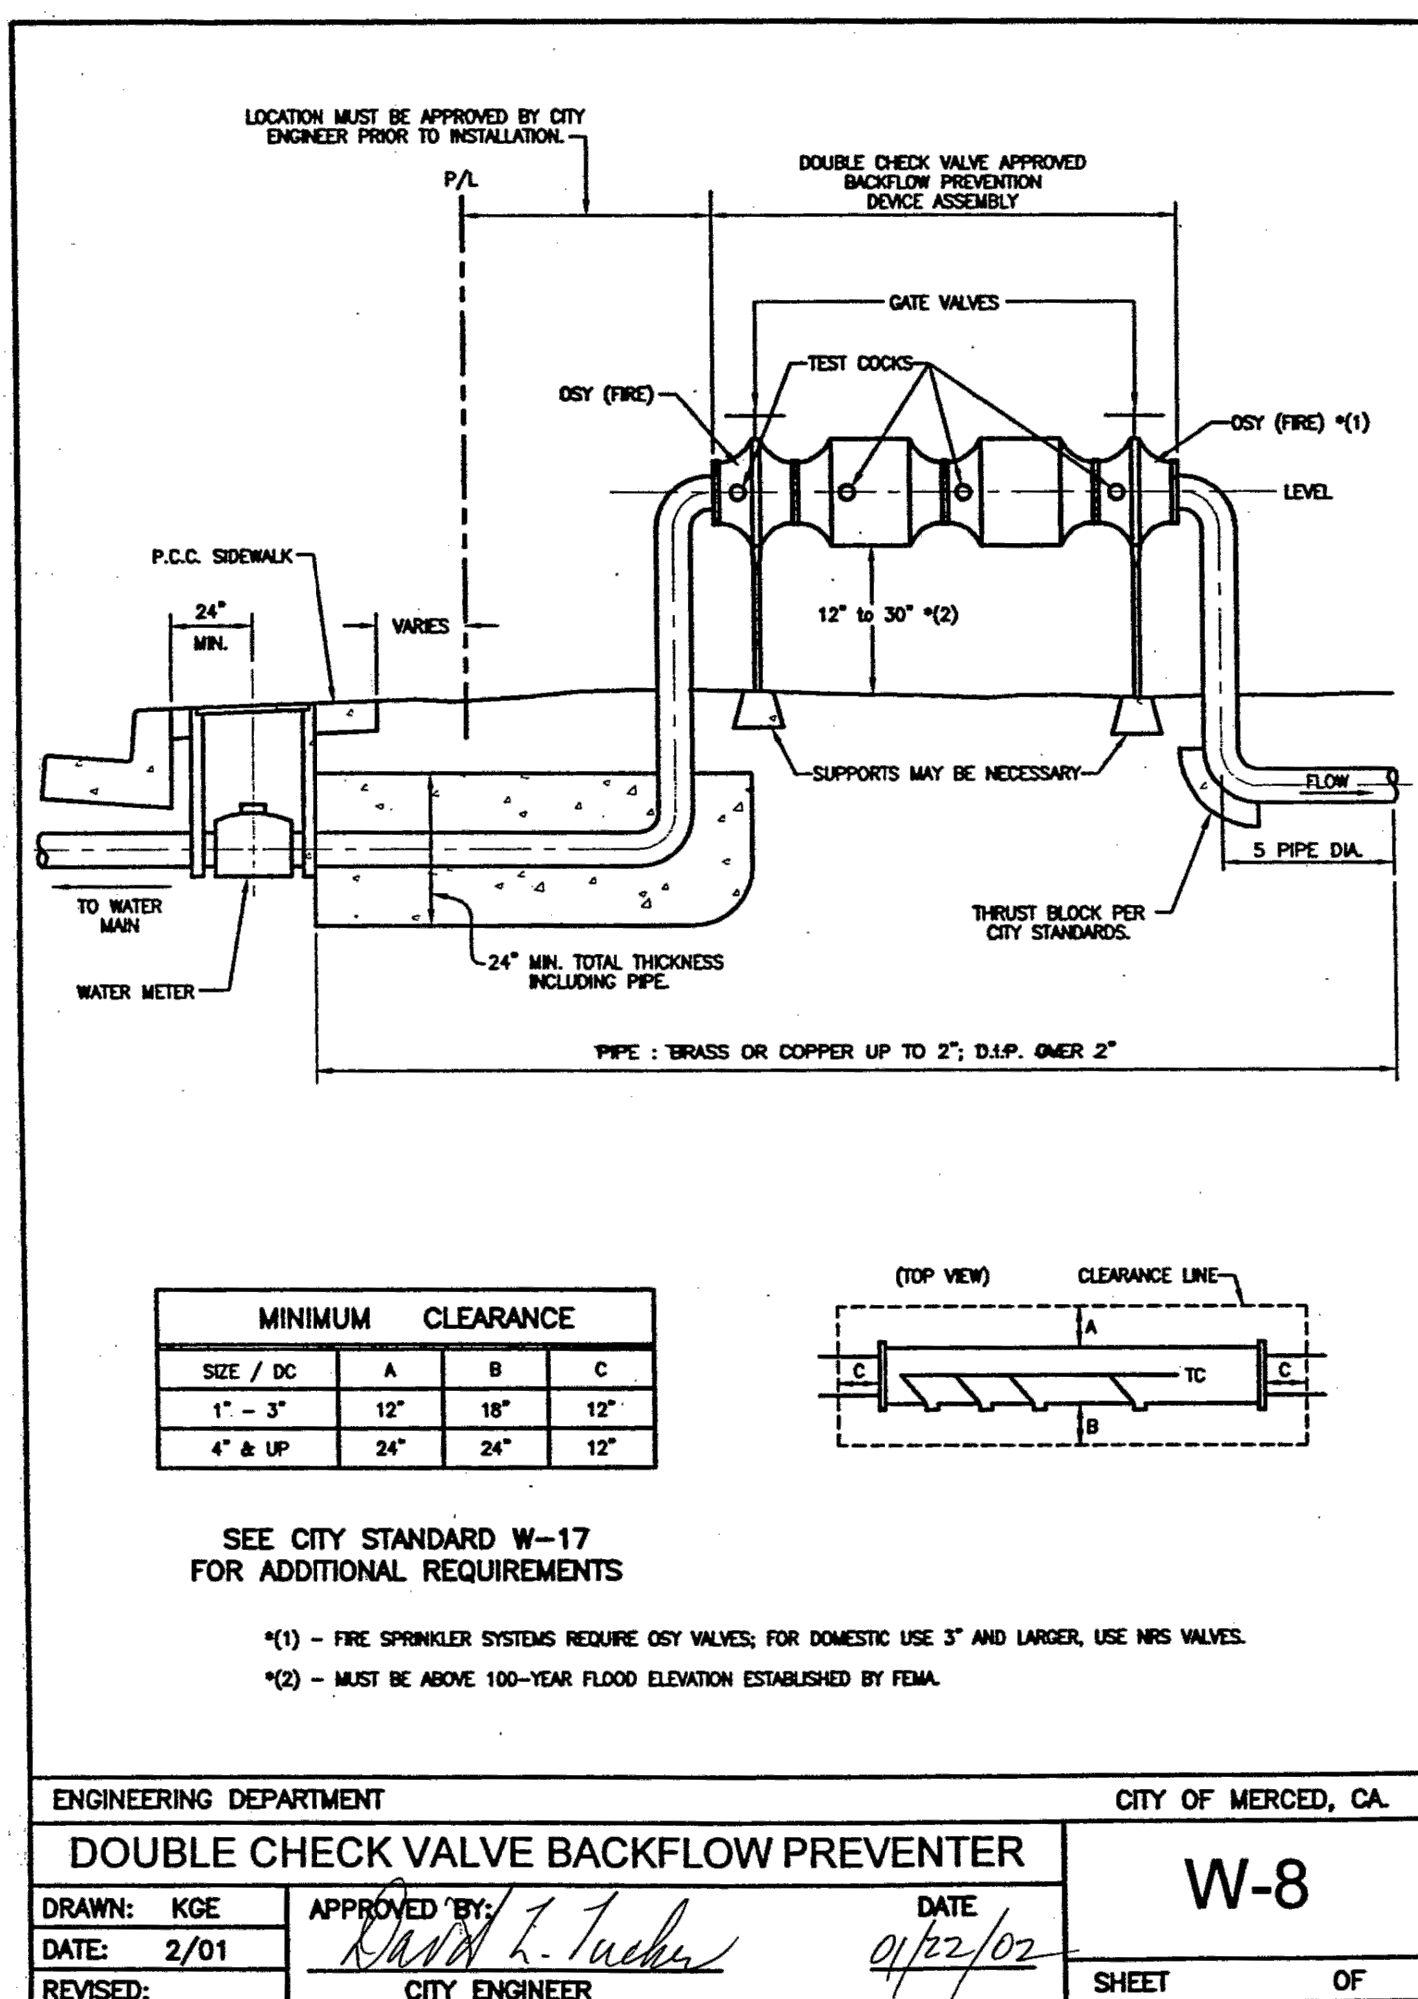

D DOUBLE CHECK VALVE BACKFLOW PREVENTER

NOT TO SCALE

JOINTS. The type of joint to be used on the respective kinds of pipe, and on valves, fittings and hydrants, shall be compression type joints installed in accordance with the manufacturer's directions.

CONNECTIONS. The contractor shall not make connections to the existing water mains. Any construction on existing in-service mains shall be accomplished by City forces at the expense of the applicant. Only one connection will be made to the existing system until the new system has been approved as provided herein under "Testing and Sterilization."

OPERATION OF VALVES. The contractor will not be permitted to operate any valves in the existing system. The City of Merced Water Department shall be notified of the requirements, and they will operate the necessary valves upon request.

WELL DESTRUCTION. Any well on-site must be abandoned in accordance with California Department of Water Resource Bulletin No. 74-81, or install an approved reduced pressure principle backflow preventer in accordance with City standards prior to connection to the City water system.

BACKFLOW PREVENTERS

- Equipment to be supplied shall be on the current list of approved backflow prevention device assemblies on file with the City Engineer. Complete assembly required. (No Substitution)
- No outlet, tee, tap, or connection of any kind to or from supply pipe between water meter and device.
- Notify City Engineer 24 hours in advance of installation. Do not backfill until installation has been inspected and approved by City Engineer.
- Flush lines thoroughly to remove foreign material prior to installation.
- Device must be readily accessible for testing and maintenance.
- Discharge port (Reduced Pressure Principle Backflow Preventer) must have approved air gap.
- Protection may be necessary in areas subject to freezing.
- For a continuous supply of water, contact City Engineer for additional requirements.
- Supports must not interfere with testing or maintenance.
- Deviation from the City standard drawing will not be permitted unless approved in writing by the City Engineer.

ENGINEERING DEPARTMENT			CITY OF MERCED, CALIF.	
WATER SYSTEM - CONSTRUCTION SPECIFICATIONS			W-17	
DRAWN: ENG.	APPROVED BY: CITY ENGINEER	DATE: 6-17-84	SHEET OF	


IDENTIFICATION STAMP
DIV. OF THE STATE ARCHITECT
APP: 02-123377 INC: 01
REVIEWED FOR
SS ☒ FLS ☒ ACS ☒
DATE: 11/18/2025

Teter, LLP expressly reserves its common law copyright and other property rights in these plans. Any reuse, reproduction, or other unauthorized use of these plans, drawings, or other documents, in whole or in part, for any other project without prior written authorization.

MARK	DATE	DESCRIPTION
	09/03/2025	INC. 02 DSA BACKCHECK



TETER, INC.
FRESNO HEADQUARTERS
VISALIA | BAKERSFIELD | MODESTO | SAN LUIS OBISPO
ARCHITECTS ENGINEERS CONNECTED

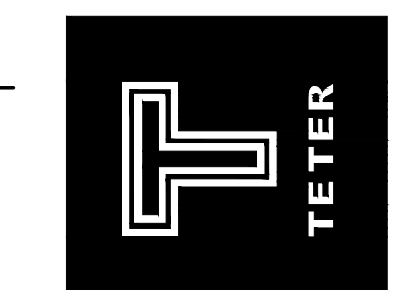

26TH STREET MARSVELO-P FACILITY
MERCED CITY SCHOOL DISTRICT
2600 K STREET
MERCED, CA 95348
DRAWING TITLE
DETAILS

PROJECT NO.
24-13084.00

DRAWING
X106-01

Blair Church & Flynn
CONSULTING ENGINEERS
461 Davis Avenue, Suite 200
Clovis, California 93612
Tel (559) 326-1400
Fax (559) 326-1300



ABBREVIATIONS

ABBREVIATIONS, WHEN USED IN THESE DOCUMENTS SHALL CONFORM TO THE FOLLOWING LIST UNLESS OTHERWISE NOTED. DRAWINGS OF OTHER DISCIPLINES (SUCH AS CIVIL, STRUCTURAL, PLUMBING, MECHANICAL, AND ELECTRICAL) MAY CONTAIN SPECIFIC ABBREVIATIONS, REFERENCES, AND LEGENDS WITH INTERPRETATION INTENDED ONLY FOR THOSE DISCIPLINES.

A	AND	FA	FIRE ALARM	OCC	OCCUPANT LOAD
L	ANGLE	F.B.	FLAT BAR	O.C.	ON CENTER
@	AT	F.B.O.	FURNISHED BY OWNER/OTHERS	O.D.	OUTSIDE DIAMETER/ DIMENSION
℄	CENTERLINE	F.D.	FLOOR DRAIN	OFF.	OFFICE
∅	DIAMETER OR ROUND	F.D.C.	FIRE DEPARTMENT CONNECTION	OFDI	OWNER FURNISHED, CONTR. INSTALLED
L	PERPENDICULAR	FDN	FOUNDATION	OFOI	OWNER FURNISHED, OWNER INSTALLED
#	POUND OR NUMBER	F.E.	FIRE EXTINGUISHER		OVER FLOW ROOF DRAIN
(E)	EXISTING	F.E.C.	FIRE EXTINGUISHER CABINET	O.F.R.D.	
(N)	NEW	F.F.	FACTORY FINISH	O.H.	OPPOSITE HAND
		F.F.LR.	FINISH FLOOR	O.H.C.D.	OVER HEAD COLING DOOR
ABV.	ABOVE	F.G.	FINISH GRADE	O.H.M.S.	OVAL HEAD MACH. SCREW
A/C	AIR CONDITIONING	F.H.	FIRE HYDRANT	O.H.W.S.	OVAL HEAD WOOD SCREW
ACP	ASPHALT CONCRETE	FHMS	FLAT HEAD MACHINE SCREW		FLAT HEAD WOOD SCREW
ACST.	ACOUSTICAL	FHWVS			
A.C.T.	ACOUSTIC CEILING TILE				
A.B.	ANCHOR BOLT	FIN.	FINISH	OPNG.	OPENING
ADA	AMERICANS WITH DISABILITIES ACT	FIXT.	FIXTURE	OPP.	OPPOSITE
ADAAG	ADA ACCESSIBLE GUIDELINES	FLR.	FLOOR(ING)	O'	OVER
ADOL.	ADDITIONAL	FLASH.	FLASHING	ORIS.	ORIGINAL
ADJ.	ADJUSTABLE	FLUOR.	FLUORESCENT	OWJ	OPEN WEB JOIST
ADJC.	ADJACENT	F.O.	FACE OF		
A.F.F.	ABOVE FINISH FLOOR	F.O.C.	FACE OF CONCRETE	P.B.N.	PLYWOOD BOUNDARY
A.F.G.	ABOVE FINISH GRADE	F.O.F.	FACE OF FINISH		NAILING
AGG.	AGGREGATE	F.O.M.	FACE OF MASONRY	P.E.N.	PLYWOOD EDGE
ALT.	ALTERNATE	F.O.S.	FACE OF STUD		NAILING
ALUM.	ALUMINUM	FRP	FIBERGLASS REINFORCED PANELING	P.E.S.	PLYWOOD EDGE
ANOD.	ANODIZED	F.S.	FIRE SPRINKLER(S)	P.I.V.	POST INDICATOR VALVE
A.P.C.	ACOUSTIC PANEL CEILING	F.S.H.	FIRE SPRINKLER HEAD		
		FT.	FOOT/FEET	P.LAM.	PLASTIC LAMINATE
APPROX.	APPROXIMATE	FURR.	FURRING	P.L.	PROPERTY LINE
ARCH.	ARCHITECT(URAL)	FUT.	FUTURE	PLAS.	PLASTER
AV	AUDIO VISUAL			PLYWD.	PLYWOOD
				PL.	PAIR
		GA.	GAUGE	PSF	POUNDS PER SQUARE FOOT
BD.	BOARD	GALV.	GALVANIZED	PSI	POUNDS PER SQUARE INCH
BEL.	BELOW	G.B.	GRAB BAR		POINT
B.E.N	BOUNDARY EDGE NAILING	G.C.	GENERAL CONTR. GENERAL	P.T.D.	PAPER TOWEL DISP.
		GEN.	GENERAL	P.T.D.F.	PRESSURE TREATED DOUGLAS FIR
BLDG.	BUILDING	G.I.	GALVANIZED IRON		
BLK.	BLOCK	GL.	GLASS	PTN.	PARTITION
BLKG.	BLOCKING	OND.	GROUND	PVC	POLYVINYL CHLORIDE
BM.	BEAM	GR.	GRADE		
BOT.	BOTTOM	GYP.	GYP SUM		
BRG.	BEARING			R	RADIUS
BTWN.	BETWEEN			R	THERMAL RESISTANCE
B.U.R.	BUILT-UP ROOF(ING)	H.B.	HOSE BIBB	R.A.	RETURN AIR
		HBD.	HARBORBOARD	R.D.	ROOF DRAIN
C&G	CURB AND GUTTER	H.C.	HOLLOW CORE	REFL.	REFLECTED
CAB.	CABINET	HD.	HEAD	REFR.	REFRIGERATOR
C.B.	CARRIAGE BOLT	H.D.	HEAVY DUTY	REINF.	REINFORCED
CEM.	CEMENT	HDR.	HEADER	REM.	REMOVE
CER.	CERAMIC	HDW.	HARDWARE	REQD.	REQUIRED
C.F.	CUBIC FOOT	HDWD.	HARDWOOD	RESIL.	RESILIENT
C.I.	CAST IRON	H.M.	HOLLOW METAL	R.H.	RIGHT HAND
C.J.	CONSTRUCTION JOINT	H.M.D.	HOLLOW METAL DOOR	R.H.W.S.	ROUND HEAD WOOD SCREW
C.L.	CENTER LINE	H.M.F.	HOLLOW METAL FRAME	RM.	ROOM
C.L.F.	CHAIN LINK FENCE			R.D.	ROUGH OPENING
CLS.	CEILING	HORIZ.	HORIZONTAL	R.O.W.	RIGHT-OF-WAY
CLO.	CLOSET	HR.	HOUR	RWD.	REDWOOD
CLR.	CLEAR	HT.	HEIGHT	RWL.	RAIN WATER LEADER
CLRM.	CLASS ROOM	HVAC	HEATING/VENTILATING COND. ITIONING	S	SOUTH
CMU	CONCRETE MASONRY UNIT	HWY	HIGH WAY	S.A.	SUPPLY AIR
				S.C.	SOLID CORE
CTR.	COUNTER			SCH.	SCHEDULE
COL.	COLUMN			S.D.	STORM DRAIN
CONC.	CONCRETE			SECT.	SECTION
CONN.	CONNECTION	I.D.	INSIDE DIAMETER/ DIMENSION	SF	SQUARE FEET/FOOT
CONSTR.	CONSTRUCTION	INFO	INFORMATION	SHR.	SHOWER
CONT.	CONTINUOUS	INSUL.	INSULATION	SHTG.	SHEATHING
CONTR.	CONTRACTOR	INT.	INTERIOR	SM.	SIMILAR
CPT.	CARPET			S.M.	SHEET METAL
CRC	COLD ROLLED CHANNEL	JAN.	JANITOR	S.O.G.	SLAB-ON-GRADE SPECIFICATION(S)
		JT.	JOINT	SPKR.	SPEAKER
CTR.	CENTER	KIT.	KITCHEN	SQ.	SQUARE
CTSK	COUNTERSUNK	K.O.	KNOCK OUT	S.S.	STAINLESS STEEL
C.Y.	CUBIC YARD	K.O.P.	KNOCK OUT PANEL	STA.	STATION
				STC	SOUND TRANS.
D.A.	DISABLED ACCESS			STD.	MISSION CLASS STANDARD
DBL.	DOUBLE	LAB.	LABORATORY	STL.	STEEL
DEMO	DEMOLISH/ DEMOLITION	LAM.	LAMINATE	STOR.	STORAGE
		LAV.	LAVATORY	STRUCT.	STRUCTURAL
D.F.	DRINKING FOUNTAIN OR DOUGLAS FIR	LBS(S)	POUND (POUNDS)	SUSP.	SUSPENDED
DET.	DETAIL	L.B.	LAG BOLT	S.W.	SIDE WALK
DIAG.	DIAGONAL	L.F.	LINEAL FOOT	SYM.	SYMMETRICAL
DIA.	DIAMETER	L.H.	LEFT HAND		
DIM.	DIMENSION	L.B.	LIBRARY		
DISP.	DISPENSER	L.T.	LIGHT		
DN.	DOWN	LT.WT.	LIGHT WEIGHT		
DP.	DEEP			T.C.	TOP OF CONCRETE
DS	DOWN SPOUT			TEMP.	TEMPORARY
DWG (S)	DRAWING	MACH.	MACHINE	TMPO.	TEMPERED
DWR.	DRAWER	MAINT.	MAINTENANCE	T&G	TONGUE AND GROOVE
		MAX.	MAXIMUM	THD.	THREADED
E	EAST	M.B.	MACHINE BOLT	THK.	THICK
EA.	EACH	M.B.M.	METAL BUILDING MANUFACTURER	T.I.	TENANT IMPROVEMENT
E.F.	EXHAUST FAN			TK.BD.	TACK BOARD
EGR.	ENGINEER	MED.	MEDICAL	T.O.S.	TOP OF STEEL
E.J.	EXPANSION JOINT	MEMB.	MEMBRANE	T.P.	TOP OF PAVEMENT
EL.	ELEVATION	MET.	METAL	TS	TUBE STEEL
ELEC.	ELECTRICAL	MFR.	MANUFACTURER	TEL.	TELEPHONE
ELEV.	ELEVATOR	MH.	MANHOLE	TTB	TELEPHONE TERM.
EMB.	EMBEDMENT	MKR.	MARKER		NAL BACK BD.
EMER.	EMERGENCY	MIN.	MINIMUM	TV	TELEVISION
E.N.	EDGE NAILING	MISC.	MISCELLANEOUS	Typ.	TYPICAL
ENCL.	ENCLOSURE	M.O.	MASONRY OPENING		
EQ.	EQUAL	MTD.	MOUNTED		
EQUIP.	EQUIPMENT	MTG.	MEETING	U.G.	UNDERGROUND
EVAP.	EVAPORATIVE	MULL.	MULLION	U.N.O.	UNLESS NOTED OTHERWISE
E.W.	EACH WAY			UR.	URNAL
EXH.	EXHAUST	N	NORTH		
EXT.	EXISTING	N.I.C.	NOT IN CONTRACT		
EXP.	EXPANSION	NO.	NUMBER	VCT.	VINYL COMPOSITION TILE
EXT.	EXTERIOR	NOM.	NOMINAL	VERT.	VERTICAL
		N.R.C.	NOISE REDUCTION COEFFICIENT	VTR	VENT TO ROOF
		N.T.S.	NOT TO SCALE	VWC	VINYL WALL COVERING

CODES AND ORGANIZATIONS

CBC	CALIFORNIA BUILDING CODE	W	WEST OR
CEC	CALIFORNIA ELECTRICAL CODE	W/	WIDTHWIDE
CFC	CALIFORNIA FIRE CODE	W.C.	WATER CLOSET
CMC	CALIFORNIA MECHANICAL CODE	W.CH.	WHEEL CHAIR
CPC	CALIFORNIA PLUMBING CODE	WD.	WOOD
DSA	DIVISION OF THE STATE ARCHITECT	WDW.	WINDOW
ICBO	INTERNATIONAL CONFERENCE OF BUILDING OFFICIALS	WF	WIDE FLANGE
		W.H.	WATER HEATER
NSF	NATIONAL SANITATION FOUNDATION	W/O	WITHOUT
NFPA	NATIONAL FIRE PROTECTION ASSOCIATION	W.P.	WATERPROOF
NEC	NATIONAL ELECTRICAL CODE	W.S.	WOOD SCREW
		WT.	WEIGHT
		WWF	WELDED WIRE FABRIC
		XFMR	TRANSFORMER

TYPICAL SYMBOLS

SYMBOLS

∠	ANGLE
∅	DIAMETER OR ROUND
⊥	PERPENDICULAR
&	AND
@	AT
⊢	CENTER LINE
#	POUND OR NUMBER
1	STATION LINE
A	DOOR SYMBOL
000A	DOOR REFERENCE
A	WINDOW SYMBOL
A	WINDOW REFERENCE
00.00	KEYNOTE SYMBOL
00.00	KEYNOTE REFERENCE, REFER TO KEYNOTE LIST ON SHEET
•	WORK POINT, CONTROL POINT OR DATUM POINT
00	WALL SYMBOL
00	WALL REFERENCE
XX XXXX	SECTION
XX XXXX	LOCATION ON SHEET REFERENCED
XX XXXX	SHEET NUMBER WHERE SECTION IS LOCATED
XX XXXX	LOCATION ON SHEET REFERENCED
XX XXXX	SHEET NUMBER WHERE DETAIL IS LOCATED
ROOM 01	ROOM IDENTIFICATION
ROOM 01	ROOM NAME
ROOM 01	ROOM NUMBER
+10'-0"	CEILING HEIGHT


IDENTIFICATION STAMP
DIV. OF THE STATE ARCHITECT
APP: 02-123377 INC: 01
REVIEWED FOR
SS ☒ FLS ☒ ACS ☒
DATE: 11/18/2025

Teter, Inc. expressly reserves its common law copyright and other property rights in these plans. This document, the ideas and designs incorporated herein, as an instrument of professional service, is not to be used for any other project without prior written authorization.

MARK	DATE	DESCRIPTION
	09/03/2025	INC. 02 DSA BACKCHECK



TETER, INC.
FRESNO HEADQUARTERS
VISALIA | BAKERSFIELD | MODESTO | SAN LUIS OBISPO
ARCHITECTS ENGINEERS CONNECTED

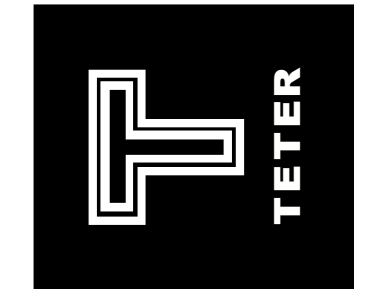

26TH STREET MARSELO-P FACILITY
MERCED CITY SCHOOL DISTRICT
2600 K STREET
MERCED, CA 95348
DRAWING TITLE
LEGENDS AND ABBREVIATIONS

PROJECT NO.
24-13084.00
DRAWING
A000-01

FOR REFERENCE ONLY

SITE INFORMATION

OWNER: MERCED CITY SCHOOL DISTRICT
ASMT: 030022008000
GIS ACRES: 0.69
GIS SQDT: 30,000.00
APN: 030022008
PARCEL: 088
PARCEL NUMBER: 030-022-008

KEYNOTES

- 2.06 EXISTING OVERHEAD UTILITY LINES TO REMAIN
2.11 EXISTING UTILITY POLE TO REMAIN
10.11 PARKING LOT TOW AWAY SIGN, SEE DETAIL 6/A110-02
10.16 NEW ACCESSIBLE PARKING SIGNAGE
10.17 "DO NOT ENTER" SIGN
10.19 PROVIDE SIGNAGE MOUNTED TO GATE. SIGN TO READ "PARKING LOT IS NOT A PASS-THROUGH FOR FIRE TRUCK", SEE DETAIL 5/A110-02
10.61 SURFACE MOUNTED KNOX BOX EMERGENCY SERVICES KEY STORAGE, COORDINATE SIZE, LOCATION, AND MOUNTING WITH LOCAL FIRE AUTHORITY AND DISTRICT
10.83 FLAGPOLE, SEE DETAIL 5/A110-02
26.11 NEW EV CHARGING STATION
28.12 GATE CONTROL AND PEDESTAL
32.24 CONCRETE STEPS
32.34 DETECTABLE WARNING SURFACE
32.41 ANGLED PARKING PER MERCED CITY STANDARDS 18.38.070
32.42 BUS TURNOUT PER CITY STANDARD TC-12
32.54 22' - 0" MOTORIZED DECORATIVE METAL ROLLING GATE
32.55 18' - 0" MOTORIZED DECORATIVE METAL ROLLING GATE
32.75 BICYCLE RACK, SEE DETAIL 3/A110-02

LEGEND

- (N) PROPOSED BUILDING
(E) AC PAVING TO REMAIN, AT ALLEY WAY
(E) CONC. PAVING TO REMAIN
(N) CONC. PAVING
(N) HEAVY DUTY CONC. PAVING
(N) AC PAVING
(N) TURF
(N) LANDSCAPING MATERIAL TO BE DETERMINE
(N) COBBLE IMPROVEMENTS
(N) CHAINLINK FENCE
(N) DECORATIVE METAL FENCE
(E) TREE TO REMAIN
(N) TREE
(E) F.H. EXISTING FIRE HYDRANT
--- ASSUMED PROPERTY LINE
--- ACCESSIBLE ROUTE (2022 C.B.C. SECTION 11B - 206)

GATE SCHEDULE					
MARK	CLEAR WIDTH	HEIGHT	MATERIAL	REMARKS	
G-1	20' - 0"	6' - 0"	DECORATIVE/ ROLLING GATE	B	
G-2	20' - 0"	6' - 0"	DECORATIVE/ ROLLING GATE	B	
G-3	4' - 0"	6' - 0"	DECORATIVE	A,C	
G-4	4' - 0"	6' - 0"	DECORATIVE	A,C	
G-5	8' - 0"	6' - 0"	DECORATIVE	A	
G-6	10' - 0"	6' - 0"	DECORATIVE	B	
G-7	4' - 0"	6' - 0"	DECORATIVE	B	
G-8	4' - 0"	6' - 0"	DECORATIVE	B	
G-9	4' - 0"	6' - 0"	SOLID UTILITY YARD GATE	B	
G-10	4' - 0"	6' - 0"	SOLID TRASH ENCLOSURE GATE	B	

REMARKS:
A. EGRESS GATE, PROVIDE PANIC HARDWARE, ACCESSIBLE
B. MAINTENANCE SERVICE GATE
C. ALL GATES TO HAVE LEVEL LANDINGS, 5'-0" PULL SIDE & 4'-0" PUSH SIDE, SEE 4/A110-02 FOR ACCESSIBLE MANUEVERING CLEARANCES

PARKING INFORMATION:

TOTAL NUMBER OF SPACES PROVIDED: 34

ACCESSIBLE PARKING SPACES

REQUIRED: 2: 28-50 (CBC TABLE 11B-208.2)
PROVIDED (TOTAL): 2
STANDARD ACCESSIBLE: 1
VAN ACCESSIBLE: 1

NOTE: THE NUMBER OF SPACES WITH EV CHARGING EQUIPMENT MAY BE DEDUCTED FROM THE TOTAL NUMBER OF SPACES FOR THE PURPOSE OF DETERMINING THE NUMBER OF ACCESSIBLE PARKING SPACES
REQUIRED (CBC 11B-208.1)

EV CAPABLE SPACES

REQUIRED: 8: 28-50
2 OF 8 TO BE PROVIDED WITH CHARGING EQUIPMENT (CGBSC TABLE 5.106.5.6.1)

PROVIDED:
EV CAPABLE W/O EQUIP.:
EV WITH CHARGING EQUIP.: 2

ACCESSIBLE EV CHARGING SPACES

(CBC TABLE 11B-228.3.2.1)

VAN ACCESSIBLE

REQUIRED: 1

STANDARD ACCESSIBLE

REQUIRED: 1

(NOTE: 1 STD ACCESSIBLE REQUIRED WHEN 5 OR MORE EV CHARGING STATIONS PROVIDED)

PROVIDED: 1

AMBULATORY

REQUIRED: 0

PROVIDED: 0


NOTE:

SHEET NOT REVIEWED FOR DSA ACCESS COMPLIANCE AS PART OF THIS DSA INCREMENT 1 APPLICATION. SHEET TO BE REVIEWED AS PART OF THE DSA INCREMENT 2 APPLICATION


IDENTIFICATION STAMP
DIV. OF THE STATE ARCHITECT
APP: 02-123377 INC: 01
REVIEWED FOR
SS ☒ FLS ☒ ACS ☒
DATE: 11/18/2025

Teter, Inc. expressly reserves its common law copyright and other property rights in these plans. This document, the ideas and designs incorporated herein, as an instrument of professional service, is not to be used for any other project without prior written authorization.

MARK	DATE	DESCRIPTION
	09/03/2025	INC. 02 DSA BACKCHECK

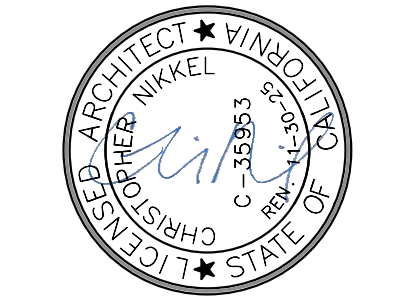

TETER, INC.
FRESNO HEADQUARTERS
VISALIA | BAKERSFIELD | MODESTO | SAN LUIS OBISPO
ARCHITECTS ENGINEERS CONNECTED

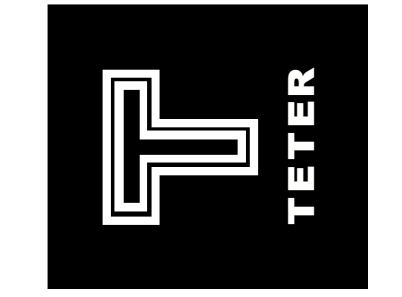

26TH STREET MARSELO-P FACILITY
MERCED CITY SCHOOL DISTRICT
2600 K STREET
MERCED, CA 95348
DRAWING TITLE
OVERALL PROPOSED SITE PLAN
FOR REFERENCE ONLY

PROJECT NO.

24-13084.00

DRAWING

A100-01


W 26TH ST.

OVERALL PROPOSED SITE PLAN



1" = 10'-0"

8

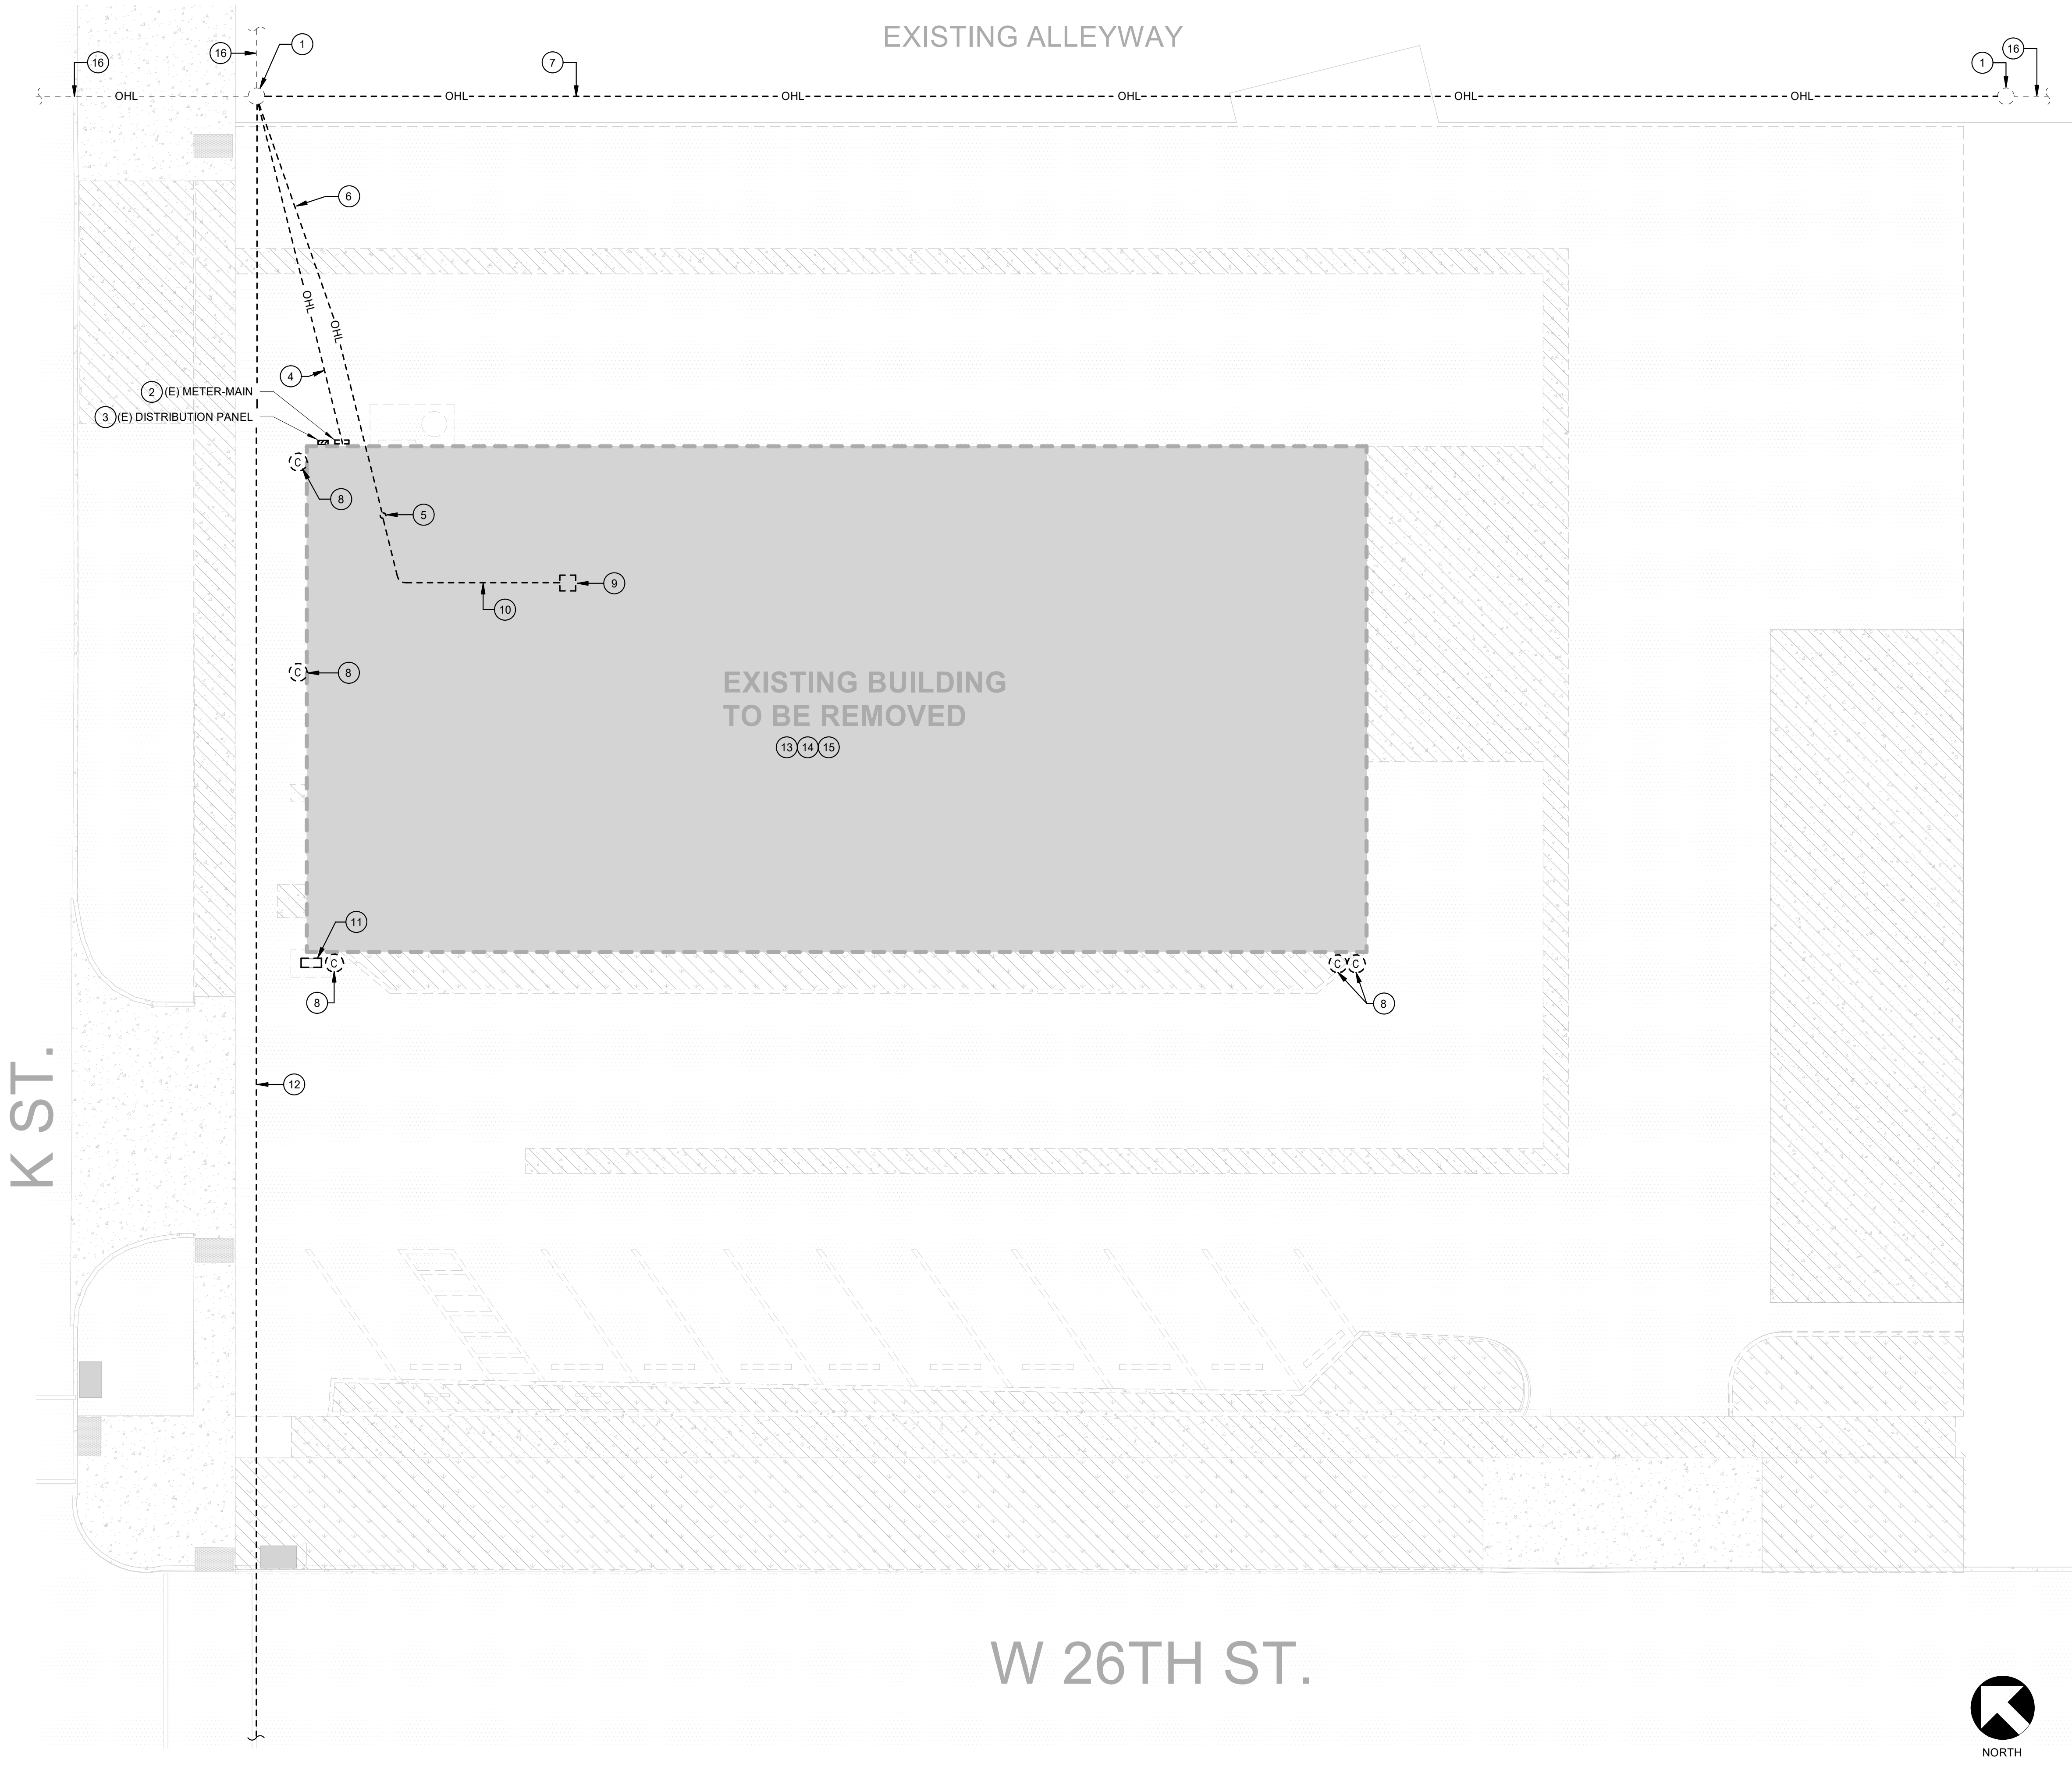

KEYNOTES

- (E) UTILITY COMPANY POLE TO REMAIN.
- DISCONNECT AND REMOVE (E) METER/MAIN. COORDINATE WITH PG&E FOR REMOVAL OF (E) METER.
- DISCONNECT AND REMOVE (E) DISTRIBUTION PANEL. REMOVE (E) FEEDER TO (E) METER/MAIN.
- (E) OVERHEAD SERVICE DROP TO BE REMOVED BY PG&E. CONTRACTOR SHALL COORDINATE WORK WITH PG&E.
- REMOVE (E) SIGNAL SERVICE WEATHERHEAD.
- (E) OVERHEAD SIGNAL SERVICE WIRING TO BE REMOVED BY COMCAST. CONTRACTOR SHALL COORDINATE WORK WITH COMCAST.
- (E) OVERHEAD POWER AND SIGNAL LINES TO BE UNDERGROUNDED. COORDINATE REMOVAL WITH PG&E AND COMCAST.
- DISCONNECT AND REMOVE (E) SECURITY CAMERA AND RETURN TO OWNER.
- (E) MPOE TO BE REMOVED BY COMCAST. (E) MDF TO BE REMOVED BY OWNER.
- (E) SIGNAL SERVICE WIRING IN ATTIC TO BE REMOVED BY COMCAST. CONTRACTOR SHALL COORDINATE WORK WITH COMCAST.
- (E) PG&E GAS SERVICE TO BE REMOVED BY PG&E. CONTRACTOR SHALL COORDINATE WORK WITH PG&E.
- (E) PG&E OVERHEAD STREETLIGHT CONDUCTOR SUPPLYING (E) STREETLIGHT ON THE SOUTH SIDE OF 26TH STREET TO BE UNDERGROUNDED.
- DISCONNECT AND REMOVE (E) SUB-PANELS THROUGHOUT BUILDING. TYPICAL OF (4). REMOVE (E) FEEDERS BACK TO (E) DISTRIBUTION PANEL AT BUILDING EXTERIOR.
- DISCONNECT AND REMOVE (E) RECEPTACLES AND EQUIPMENT POWER CONNECTIONS THROUGHOUT BUILDING. REMOVE (E) BRANCH CIRCUITS BACK TO SOURCE.
- DISCONNECT AND REMOVE (E) LIGHTING FIXTURES AND LIGHTING CONTROLS THROUGHOUT BUILDING. REMOVE (E) BRANCH CIRCUITS BACK TO SOURCE.
- PORTION OF (E) OVERHEAD POWER AND SIGNAL LINES TO REMAIN.


DEMOLITION NOTES

- A. ELECTRICAL FACILITIES SHOWN DASHED ARE EXISTING:
- THOSE SHOWN LIGHTWEIGHT (FADED) SHALL REMAIN AND REQUIRE MODIFICATION AS NOTED.
 - THOSE SHOWN HEAVYWEIGHT (DARK) REQUIRE REMOVAL OR RELOCATION AS NOTED.
- B. EXISTING ELECTRICAL FACILITIES AND CIRCUITING SHOWN ARE BASED ON LIMITED RECORD DRAWINGS AND LIMITED SITE VISITS. THE DRAWINGS MAY NOT ACCURATELY REPRESENT ACTUAL EXISTING CONDITIONS IN THE FIELD. THE CONTRACTOR SHALL FIELD VERIFY ALL EXISTING CONDITIONS AND RING OUT EXISTING CIRCUITS TO DETERMINE EXACT ROUTING.

IDENTIFICATION STAMP
DIV. OF THE STATE ARCHITECT
APP: 02-123377 INC: 01
REVIEWED FOR
SS ☒ FLS ☒ ACS ☒
DATE: 11/18/2025


Teter, Inc. expressly reserves its common law copyright and other property rights in these plans. This document, the ideas and designs incorporated herein, as an instrument of professional service, is not to be used for any other project without prior written authorization.

MARK	DATE	DESCRIPTION
	09/03/2025	INC. 02 DSA BACKCHECK

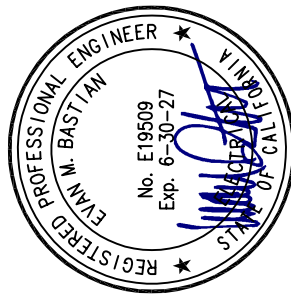

TETER, INC.

FRESNO HEADQUARTERS
VISALIA | BAKERSFIELD | MODESTO | SAN LUIS OBISPO
ARCHITECTS ENGINEERS CONNECTED

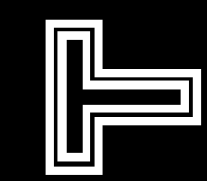


26TH STREET MARSELO-P FACILITY
MERCED CITY SCHOOL DISTRICT
2600 K STREET
MERCED, CA 95348

DRAWING TITLE
DEMOLITION ELECTRICAL SITE PLAN

PROJECT NO.
24-13084.00

 DRAWING
E100-01



CODES, RULES & REGULATIONS		
ALL WORK SHOWN HEREIN SHALL COMPLY WITH THE CURRENT REGULATIONS OF THE CALIFORNIA STATE FIRE MARSHAL, CALIFORNIA BUILDING CODE, TITLES 8 AND 19 THROUGH 24, SERVING UTILITY RULES AND ALL OTHER APPLICABLE STATE ORDINANCES. NOTHING IN THESE PLANS OR SPECIFICATIONS SHALL BE INTERPRETED AS TO PERMIT ANY WORK NOT IN CONFORMANCE WITH THESE CODES, RULES AND REGULATIONS. WHERE WORK OF A GREATER DEGREE IS INDICATED IN THESE PLANS OR SPECIFICATIONS, THAT REQUIREMENT SHALL GOVERN SUCH WORK.		
C.E.C. TITLE 24 COMPLIANCE		
THE LIGHTING AND LIGHTING CONTROL SYSTEMS DESIGN DEPICTED HEREIN IS IN COMPLIANCE WITH REQUIREMENTS OF THE CURRENT CALIFORNIA ENERGY COMMISSION EFFICIENCY STANDARDS FOR NONRESIDENTIAL BUILDINGS.		
GENERAL NOTES (TYPICAL)		
1. REFER TO THE ARCHITECTURAL REFLECTED CEILING PLAN FOR THE EXACT LOCATION OF ALL CEILING MOUNTED ELECTRICAL EQUIPMENT.		
2. REFER TO THE MECHANICAL AND PLUMBING PLANS FOR THE EXACT LOCATION OF ALL MECHANICAL, HVAC AND PLUMBING EQUIPMENT.		
3. COORDINATE ELECTRICAL PANEL AND TERMINAL CABINET LOCATIONS AND ROUTING OF UNDERGROUND CONDUITS WITH THE ARCHITECTURAL AND STRUCTURAL DRAWINGS PRIOR TO COMMENCEMENT OF ANY ROUGH-IN WORK FOR THIS EQUIPMENT.		
4. COORDINATE ALL ELECTRICAL WORK WITH OTHER TRADES WHOSE WORK WILL IMPACT PLACEMENT OR CONNECTION OF ELECTRICALLY POWERED EQUIPMENT REGARDLESS OF RESPONSIBILITY FOR SUPPLYING EQUIPMENT.		
MEP COMPONENT ANCHORAGE NOTE		
ALL MECHANICAL, PLUMBING, AND ELECTRICAL COMPONENTS SHALL BE ANCHORED AND INSTALLED PER THE DETAILS ON THE DSA APPROVED CONSTRUCTION DOCUMENTS. THE FOLLOWING COMPONENTS SHALL BE ANCHORED OR BRACED TO MEET THE FORCE AND DISPLACEMENT REQUIREMENTS PRESCRIBED IN THE 2022 CBC, SECTIONS 1617A.1-18 THROUGH 1617A.1,26 AND ASCE 7-16 CHAPTERS 13, 26 AND 30.		
1. ALL PERMANENT EQUIPMENT AND COMPONENTS.		
2. TEMPORARY, MOVEABLE OR MOBILE EQUIPMENT THAT IS PERMANENTLY ATTACHED (E.G. HARD WIRED) TO THE BUILDING UTILITY SERVICES SUCH AS ELECTRICITY, GAS OR WATER, "PERMANENTLY ATTACHED" SHALL INCLUDE ALL ELECTRICAL CONNECTIONS EXCEPT PLUGS FOR 110/220 VOLT RECEPTACLES HAVING FLEXIBLE CABLE.		
3. TEMPORARY, MOVABLE OR MOBILE EQUIPMENT EQUIPMENT WHICH IS HEAVIER THAN 400 POUNDS OR HAS A CENTER OF MASS LOCATED 4 FEET OR MORE ABOVE THE ADJACENT FLOOR OR ROOF LEVEL THAT DIRECTLY SUPPORT THE COMPONENT IS REQUIRED TO BE RESTRAINED IN A MANNER APPROVED BY DSA.		
THE FOLLOWING MECHANICAL AND ELECTRICAL COMPONENTS SHALL BE POSITIVELY ATTACHED TO THE STRUCTURE BUT NEED NOT DEMONSTRATE DESIGN COMPLIANCE WITH THE REFERENCES NOTED ABOVE. THESE COMPONENTS SHALL HAVE FLEXIBLE CONNECTIONS PROVIDED BETWEEN THE COMPONENT AND ASSOCIATED DUCTWORK, PIPING, AND CONDUIT. FLEXIBLE CONNECTIONS MUST ALLOW MOVEMENT IN BOTH TRANSVERSE AND LONGITUDINAL DIRECTIONS:		
A. COMPONENTS WEIGHING LESS THAN 400 POUNDS AND HAVE A CENTER OF MASS LOCATED 4 FEET OR LESS ABOVE THE ADJACENT FLOOR OR ROOF LEVEL THAT DIRECTLY SUPPORT THE COMPONENT.		
B. COMPONENTS WEIGHING LESS THAN 20 POUNDS, OR IN THE CASE OF DISTRIBUTED SYSTEMS, LESS THAN 5 POUNDS PER FOOT, WHICH ARE SUSPENDED FROM A ROOF OR FLOOR OR HUNG FROM A WALL.		
THE ANCHORAGE OF ALL MECHANICAL, ELECTRICAL AND PLUMBING COMPONENTS SHALL BE SUBJECT TO THE APPROVAL OF THE DESIGN PROFESSIONAL IN GENERAL RESPONSIBLE CHARGE OR STRUCTURAL ENGINEER DELEGATED RESPONSIBILITY AND ACCEPTANCE BY DSA. THE PROJECT INSPECTOR WILL VERIFY THAT ALL COMPONENTS AND EQUIPMENT HAVE BEEN ANCHORED IN ACCORDANCE WITH THE ABOVE REQUIREMENTS.		
PIPING, DUCTWORK, AND ELECTRICAL DISTRIBUTION SYSTEM BRACING NOTE:		
PIPING, DUCTWORK, AND ELECTRICAL DISTRIBUTION SYSTEMS SHALL BE BRACED TO COMPLY WITH THE FORCES AND DISPLACEMENTS PRESCRIBED IN ASCE 7-16 SECTION 13.3 AS DEFINED IN ASCE 7-16 SECTION 13.6.5, 13.6.6, 13.6.7, 13.6.8; AND 2022 CBC, SECTIONS 1617A.1,24, 1617A.1,25, AND 1617A.1,26.		
THE METHOD OF SHOWING BRACING AND ATTACHMENTS TO THE STRUCTURE FOR THE IDENTIFIED DISTRIBUTION SYSTEM ARE AS NOTED BELOW. WHEN BRACING AND ATTACHMENTS ARE BASED ON A PREAPPROVED INSTALLATION GUIDE (E.G., OSHPD OPM FOR 2013 CBC OR LATER), COPIES OF THE BRACING SYSTEM INSTALLATION GUIDE OR MANUAL SHALL BE AVAILABLE ON THE JOBSITE PRIOR TO THE START OF AND DURING THE HANGING AND BRACING OF THE DISTRIBUTION SYSTEMS. THE STRUCTURAL ENGINEER OF RECORD SHALL VERIFY THE ADEQUACY OF THE STRUCTURE TO SUPPORT THE HANGER AND BRACE LOADS.		
MECHANICAL PIPING (MP), MECHANICAL DUCTS (MD), PLUMBING PIPING (PP), AND ELECTRICAL DISTRIBUTION SYSTEMS (E):		
MP ☐ MD ☐ PP ☐ E ☒ OPTION 1: DETAILED ON THE APPROVED DRAWINGS WITH PROJECT SPECIFIC NOTES AND DETAILS		
MP ☐ MD ☐ PP ☐ E ☐ OPTION 2: SHALL COMPLY WITH HCAI (OSHPD) PREAPPROVAL (OPM#) _____, AS INCLUDED IN THESE DRAWINGS WITH PROJECT-SPECIFIC NOTES AND DETAILS.		
GENERAL NOTES		N.T.S. 11

ELECTRICAL SYMBOL LEGEND			
DIMENSIONS INDICATED ARE MEASURED TO CENTERLINE OF ENCLOSURE, UNLESS OTHERWISE NOTED			
NOTE: SOME SYMBOLS SHOWN MAY NOT APPLY TO THIS PROJECT			
SYMBOL	DESCRIPTION	SYMBOL	DESCRIPTION
E.P.	DENOTES EXPLOSION PROOF CONSTRUCTION		SINGLE POLE AC SNAP SWITCH @ +48" TO TOP OF BOX, U.O.N.
D.T.	DENOTES DUST TIGHT CONSTRUCTION		TWO POLE AC SNAP SWITCH @ +48" TO TOP OF BOX, U.O.N.
O.C.	DENOTES SPACING DIMENSION ON CENTER LINE OF DEVICE		THREE WAY AC SNAP SWITCH @ +48" TO TOP OF BOX, U.O.N.
R.T.	DENOTES RAIN TIGHT CONSTRUCTION		FOUR WAY AC SNAP SWITCH @ +48" TO TOP OF BOX, U.O.N.
U.G.	DENOTES UNDERGROUND INSTALLATION		HORSEPOWER RATED AC SNAP SWITCH @ +48" TO TOP OF BOX U.O.N.
V.P.	DENOTES VAPOR TIGHT CONSTRUCTION		SINGLE POLE AC SNAP SWITCH WITH PILOT LAMP @ +48" TO TOP OF BOX U.O.N.
W.P.	DENOTES WEATHERPROOF CONSTRUCTION		DIGITAL TIMER SWITCH, FLUSH MOUNTED @ +48" TO TOP OF BOX U.O.N.
W.T.	DENOTES WATER TIGHT CONSTRUCTION		SINGLE POLE AC SNAP SWITCH @ +48" TO TOP OF BOX, U.O.N.
A.F.F.	DENOTES ABOVE FINISHED FLOOR		KEY OPERATED AC SNAP SWITCH @ +48" TO TOP OF BOX U.O.N.
A.F.G.	DENOTES ABOVE FINISHED GRADE		SYSTEM CONTROL SWITCH PER PLANS @ 48" TO TOP OF BOX U.O.N.
F.B.O.	DENOTES FURNISHED BY OTHERS		WALL SWITCH WITH INTEGRAL OCCUPANCY SENSOR @ +48" TO TOP OF BOX, U.O.N.
U.O.N.	DENOTES UNLESS OTHERWISE NOTED		OCCUPANCY SENSOR - CEILING MOUNTED
(E)	DENOTES EXISTING TO REMAIN, NO WORK U.O.N.		OCCUPANCY SENSOR - WALL MOUNTED @ +90" TO TOP OF BOX, U.O.N.
(N)	DENOTES NEW		LIGHTING CONTROL SYSTEM DIMMING POWER PACK MOUNTED IN ATTIC
	ELECTRICAL KEYNOTES: DENOTES KEYNOTE #1 OF NOTES ON SAME SHEET		LIGHTING CONTROL SYSTEM PLUG LOAD RELAY PACK MOUNTED IN ATTIC
A-3	CIRCUIT HOME RUN: DENOTES PANEL A, CKT. #3, - 3/4" C. MINIMUM, U.O.N.		LIGHTING CONTROL SYSTEM 2-BUTTON DIMMING WALL SWITCH @ +48" TO TOP OF BOX, U.O.N.
	CIRCUIT FEEDER: DENOTES FEEDER F'1' PER SYSTEM FEEDER SCHEDULE		LIGHTING CONTROL SYSTEM 4-BUTTON DIMMING WALL SWITCH @ +48" TO TOP OF BOX, U.O.N.
	CONDUIT IN ATTIC/WALL: DENOTES 3/4"C-2#12 AWG CU THWN, 1#12 CU GND, U.O.N.		LIGHTING CONTROL SYSTEM DIMMING WALL SWITCH WITH LOCKING COVER @ +48" TO TOP OF BOX, U.O.N.
	CONDUIT IN FLOOR/U.G.: DENOTES 3/4"C-2#12 AWG CU THWN, 1#12 CU GND, U.O.N.		LIGHTING CONTROL SYSTEM DAYLIGHT SENSOR - CEILING MOUNTED
	DENOTES EXISTING CONDUIT RUN TO REMAIN		LIGHTING CONTROL SYSTEM NETWORK BRIDGE
	CONDUIT RUN - STUBBED, CAPPED AND LABELED.		LIGHTING CONTROL SYSTEM NETWORK GATEWAY
	CONDUIT RUN: DENOTES 3/4"C - 3 #12 AWG CU THWN + 1 #12 CU GND, U.O.N.		LIGHTING CONTROL SYSTEM AUTOMATED DEMAND RESPONSE MODULE
	CONDUIT RUN: DENOTES 3/4"C - 4 #12 AWG CU THWN + 1 #12 CU GND, U.O.N.		LIGHTING CONTROL SYSTEM TIME CLOCK
	CONDUIT RUN: DENOTES 3/4"C - 5 #12 AWG CU THWN + 1 #12 CU GND, U.O.N.		PHOTOCCELL CONTROL MOUNTED ON ROOF
	CONDUIT RUN: DENOTES 1"C - 6 #12 AWG CU THWN + 1 #12 CU GND, U.O.N.		
	SEPARATE POWER AND DATA FLOOR BOXES		LOW VOLTAGE CONTROL TRANSFORMER
	FLUSH FLOOR BOX WITH DEVICE(S) INSTALLED PER PLANS, U.O.N.		
	TAMPER-RESISTANT SINGLE RECEPTACLE IN WALL @ +18", U.O.N.		ELECTRICAL PANELBOARD PER PLANS, FLUSH MOUNTED IN WALL
	TAMPER-RESISTANT DUPLEX RECEPTACLE IN WALL @ +18", U.O.N.		ELECTRICAL PANELBOARD PER PLANS, SURFACE MOUNTED ON WALL
	TAMPER-RESISTANT DUPLEX GFI RECEPTACLE, IN WALL @ 18", U.O.N.		TERMINAL CABINET PER PLANS, FLUSH MOUNTED IN WALL
	TAMPER-RESISTANT SWITCHED GFCI RECEPTACLE IN WALL @ +18" A.F.F. U.O.N. (OCC. SENSOR OR WALL SWITCH CONTROLLED)		TERMINAL CABINET PER PLANS, SURFACE MOUNTED ON WALL
	TAMPER-RESISTANT WEATHER RESISTANT (WIR) DUPLEX GFCI RECEPTACLE W/ W.P. COVER @ +18", U.O.N.		CONTROL PANEL PER PLANS, FLUSH MOUNTED IN WALL
	TAMPER-RESISTANT DUPLEX ISOLATED GROUND RECEPTACLE IN WALL @ +18", U.O.N.		CONTROL PANEL PER PLANS, SURFACE MOUNTED ON WALL
	TAMPER-RESISTANT QUADRUPEX RECEPTACLE IN WALL @ +18", U.O.N.		LIGHTING CONTROL PANEL PER PLANS, FLUSH MOUNTED IN WALL
	SPECIAL PURPOSE ELECTRICAL OUTLET PER PLAN IN WALL @ 18" U.O.N.		LIGHTING CONTROL PANEL PER PLANS, SURFACE MOUNTED ON WALL
	DUPLEX RECEPTACLE FLUSH IN CEILING		FIRE ALARM PANEL PER PLANS, FLUSH MOUNTED IN WALL
	TAMPER-RESISTANT QUADRUPEX RECEPTACLE IN WALL @ +18" A.F.F. U.O.N. ONE UNSWITCHED RECEPTACLE AND ONE SWITCHED (OCC. SENSOR CONTROLLED) RECEPTACLE		FIRE ALARM PANEL PER PLANS, SURFACE MOUNTED ON WALL
	JUNCTION BOX		
	JUNCTION BOX WITH FLEXIBLE CONDUIT CONNECTION TO EQUIPMENT		ACCESS CONTROL SYSTEM KEYPAD
	NON-FUSIBLE DISCONNECT SWITCH		
	FUSIBLE DISCONNECT SWITCH		RECESSED LED LIGHTING FIXTURE
	FUSIBLE DISCONNECT SWITCH WITH INTEGRAL MAGNETIC STARTER		RECESSED LED LIGHTING FIXTURE WITH EMERGENCY BATTERY BACKUP
	ELECTRIC MOTOR		SURFACE MOUNTED LED LIGHTING FIXTURE
	EXHAUST FAN OR FRACTIONAL HORSEPOWER MOTOR		SURFACE MOUNTED LED LIGHTING FIXTURE WITH EMERGENCY BATTERY BACKUP
	SURFACE MOUNTED RACEWAY, MOUNT @ +18" A.F.F. U.O.N.		SURFACE MOUNTED LED STRIP LIGHT
			SURFACE MOUNTED LED STRIP LIGHT WITH EMERGENCY BATTERY BACKUP
			POST TOP MOUNTED LIGHTING FIXTURE
			WALL MOUNTED LIGHTING FIXTURE
			WALL MOUNTED LIGHTING FIXTURE WITH EMERGENCY BATTERY BACKUP
			CEILING MOUNTED LIGHTING FIXTURE
			CEILING MOUNTED LIGHTING FIXTURE WITH EMERGENCY BATTERY BACKUP
			RECESSED LIGHTING FIXTURE
			RECESSED FIXTURE WITH EMERGENCY BATTERY BACKUP
			SURFACE MOUNTED ROUND LIGHTING FIXTURE
			SURFACE MOUNTED ROUND LIGHTING FIXTURE WITH EMERGENCY BATTERY BACKUP
			ILLUMINATED EXIT SIGN MOUNTED ON CEILING
			ILLUMINATED EXIT SIGN MOUNTED ON WALL
			LOW LEVEL PHOTOLUMINESCENT EXIT SIGN MOUNTED ON WALL
			POLE MOUNTED EXTERIOR LIGHTING FIXTURE
SYMBOL LEGEND		N.T.S.	3

IDENTIFICATION STAMP
DIV. OF THE STATE ARCHITECT
APP: 02-123377 INC: 01
REVIEWED FOR
SS ☒ FLS ☒ ACS ☒
DATE: 11/18/2025

Teter, Inc. expressly reserves its common law copyright and other property rights in these plans. This document, the ideas and designs incorporated herein, as an instrument of professional service, is not to be used for any other project without prior written authorization.

MARK

DATE

DESCRIPTION

09/03/2025

INC. 02 DSA BACKCHECK

TETER, INC.

FRESNO HEADQUARTERS
VISALIA | BAKERSFIELD | MODESTO | SAN LUIS OBISPO
ARCHITECTS ENGINEERS CONNECTED

26TH STREET MARSELO-P FACILITY
MERCED CITY SCHOOL DISTRICT
2600 K STREET
MERCED, CA 95348

DRAWING TITLE
ELECTRICAL NOTES & LEGEND

PROJECT NO.

24-13084.00

DRAWING

E800-01