


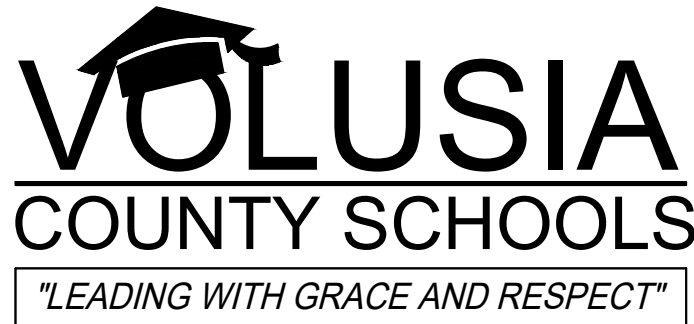

THE SCHOOL BOARD OF VOLUSIA
COUNTY FLORIDA
200 North Clara Avenue
DeLand, Florida 32720

UNIVERSITY HIGH SCHOOL EXTEND PARENT LOOP

VCS Project NO. 2548185

1000 RHODE ISLAND AVE., ORANGE CITY, VOLUSIA COUNTY,
FLORIDA 32763

SCHOOL BOARD MEMBERS

RUBEN COLON
KRISTA GOODRICH
DONNA BROSEMER
JAMIE HAYNES
JESSICA THOMPSON

CARMEN J. BALGOBIN

BOARD CHAIR
BOARD VICE CHAIR
MEMBER
MEMBER
MEMBER

SUPERINTENDENT



ALLEN C. LANE, JR., P.E.
FL. REG. NO. 60144

DESCRIPTION OF WORK

PARENT LOOP EXTENSION AND
MISCELLANEOUS LIGHTING AND SITE
IMPROVEMENTS

Architect's Statement of Compliance
To the best of my knowledge, these drawings and the project manual are complete and comply with
the Florida Building Code.

BUILDING DATA

LOCATION MAP



NOT TO SCALE

ENGINEERS & CONSULTANTS

ENGINEER
CPH CONSULTING, INC.
1117 E. ROBINSON STREET
ORLANDO, FLORIDA 32801
(407) 425-0452
BEN BUENACAMINO
bbuenacamino@cphcorp.com
WWW.CPHCORP.COM



SURVEYOR
CPH CONSULTING, INC.
500 WEST FULTON STREET
SANFORD, FLORIDA 32771
(407) 322-6841
THOMAS GALLOWAY, P.L.S.
tgalloway@cphcorp.com
WWW.CPHCORP.COM



INDEX OF DRAWINGS

- G001 COVER SHEET
- G002 GENERAL NOTES
- C100 DEMOLITION PLAN
- C101 DIMENSION AND STRIPING PLAN
- C102 DRAINAGE AND GRADING PLAN
- C500 GENERAL NOTES AND DETAILS
- E001 ELECTRICAL GENERAL NOTES
- E100 ELECTRICAL DEMOLITION PLAN
- E101 ELECTRICAL CONSTRUCTION PLAN
- E200 PHOTOMETRIC SITE PLAN
- E300 ELECTRICAL SCHEDULES & DETAILS
- V0.1 COVER SHEET
- V1.1 TOPOGRAPHIC SURVEY
- V1.2 TOPOGRAPHIC SURVEY

CONSTRUCTION DOCUMENTS 02.07.25

REVISIONS

REVISIONS	DOCUMENT HISTORY	CONFORMED SET
1/8/2026		

UNIVERSITY HIGH SCHOOL
EXTEND PARENT LOOP
VCS Project NO. 2548185
1000 RHODE ISLAND AVE., ORANGE CITY
VOLUSIA COUNTY, FLORIDA 32763

Engineer Allen C. Lane, Jr., P.E.		ARCHIVER OF RECORD
DESIGNED BY BCB	DRAWN BY BCB	
ISSUE DATE 02.07.25	AE PROJECT NUMBER 2501359	
SHEET TITLE COVER SHEET		
DRAWING NO. G001		

FOR IDENTIFICATION OF CONTRACTUAL AGREEMENTS, THIS SET OF DRAWINGS IS DATED JAN. 15, 2025. ANY REVISIONS THERE AFTER WILL BE DATED AND NOTED ON THE AFFECTED DRAWING(S).

THE CONTRACTOR SHALL EXERCISE CAUTION WHEN CROSSING AN UNDERGROUND UTILITY, WHETHER SHOWN ON THE PLANS OR LOCATED BY THE UTILITY COMPANY. ALL UTILITIES EXCLUDING VOLUSIA COUNTY POTABLE WATER THAT INTERFERE WITH THE PROPOSED CONSTRUCTION SHALL BE RELOCATED BY THE RESPECTIVE UTILITY COMPANY. THE CONTRACTOR SHALL COORDINATE ANY RELOCATION OF THE POTABLE WATER MAINS WITH THE FLUOR DANISHER COMPANY. ANY RELOCATION OF THE MAINS SHALL BE COMPLETED BY THE CONTRACTOR AND COORDINATED WITH VOLUSIA COUNTY WATER UTILITIES PRIOR TO COMPLETING THE WORK. ANY DELAY, INCONVENIENCE, OR EXPENSE CAUSED TO THE CONTRACTOR BY THE RELOCATION OF VARIOUS UTILITIES SHALL BE INCIDENTAL TO THE CONTRACT, AND NO EXTRA COMPENSATION WILL BE ALLOWED.

"Florida Law (F.S. 556) Underground Facility Damage Prevention and Safety Act mandates that excavators/contractors shall contact Sunshine 811 (fka: Sunshine State one-Call of Florida) by calling 800-432-4770 or 811 at least 2 full business days prior to beginning any excavation or demolition to allow member operators an opportunity to identify and mark their underground facilities and appropriately response to the Positive Response System."

THE CONTRACTOR SHALL CONFORM WITH ALL INSPECTION REQUIREMENTS OF THE VOLUSIA COUNTY SCHOOL BOARD AND CITY OF ORANGE CITY. FAILURE TO COMPLY WITH INSPECTION REQUIREMENTS SHALL RESULT IN NON-ACCEPTANCE OF SPECIFIC WORK ITEMS.

LAYOUT AND CONTROL:
UNLESS OTHERWISE NOTED ON THE PLANS, THE CONTRACTOR SHALL USE THE GEOMETRY PROVIDED ON THE CONSTRUCTION PLANS. BENCHMARK INFORMATION SHALL BE PROVIDED TO THE CONTRACTOR BY THE OWNER OR OWNER'S SURVEYOR. ANY DISCREPANCIES BETWEEN FIELD MEASUREMENTS AND CONSTRUCTION PLAN INFORMATION SHALL BE BROUGHT TO THE ATTENTION OF THE ENGINEER IMMEDIATELY.

SHOP DRAWINGS:
SHOP DRAWINGS AND CERTIFICATIONS FOR ALL STORM DRAINAGE PIPE AND, STRUCTURES, SPECIALTY SURFACING MATERIALS AND OTHER APPURTENANCES SHALL BE REQUIRED. THE CONTRACTOR SHALL SUBMIT SHOP DRAWINGS TO THE ENGINEER FOR APPROVAL PRIOR TO ORDERING THE MATERIALS REQUIRED FOR CONSTRUCTION.

MATERIAL SPECIFICATIONS:
ALL MATERIALS AND CONSTRUCTION METHODS ARE TO BE IN ACCORDANCE WITH FDOT STANDARD SPECIFICATIONS FOR ROAD AND BRIDGE CONSTRUCTION (LATEST EDITION), SECTION 400 (CONCRETE STRUCTURES) AND THE APPLICABLE FDOT INDEX NUMBER DETAIL AS SHOWN IN FDOT ROADWAY AND TRAFFIC DESIGN STANDARDS (LATEST EDITION).

SOAKER SWALE CONSTRUCTION: SOAKER SWALES SHALL BE EXCAVATED AS SHOWN ON THE CONSTRUCTION PLANS. IN THE EVENT THAT HARDPAN, CLAYEY, OR SILTY MATERIALS ARE ENCOUNTERED IN THE CONSTRUCTION OF THE SWALE, THE CONTRACTOR SHALL IMMEDIATELY NOTIFY THE ENGINEER FOR INSPECTION OF THE MATERIALS. THE CONTRACTOR SHALL SOD THE SOAKER SWALE PER THE CONSTRUCTION PLANS IMMEDIATELY FOLLOWING FINAL GRADING. CONTRACTOR SHALL MAINTAIN THE SOD UNTIL FINAL ACCEPTANCE BY THE OWNER/OPERATOR.

EARTHWORK

EROSION CONTROL:
EROSION AND SILTATION CONTROL MEASURES ARE TO BE PROVIDED AND INSTALLED PRIOR TO COMMENCEMENT OF CONSTRUCTION. THESE MEASURES ARE TO BE INSPECTED BY THE CONTRACTOR ON A REGULAR BASIS AND ARE TO BE MAINTAINED OR REPAIRED ON AN IMMEDIATE BASIS AS REQUIRED. REFER TO THE WATER MANAGEMENT DISTRICT PERMIT FOR ADDITIONAL REQUIREMENTS FOR EROSION CONTROL AND SURFACE DRAINAGE.

LIMITS OF DISTURBANCE:
THE LIMITS OF DISTURBANCE HAVE BEEN PROVIDED TO THE CONTRACTOR ON THE CONSTRUCTION PLANS. UNLESS OTHERWISE DIRECTED BY THE OWNER OR ENGINEER, THE CONTRACTOR IS EXPECTED TO CONTAIN ALL CONSTRUCTION ACTIVITIES WITHIN THESE LIMITS. THE CONTRACTOR SHALL NOT DISTURB SURROUNDING PROPERTIES OR TRAVEL ON SURROUNDING PROPERTIES WITHOUT WRITTEN CONSENT FROM THE PROPERTY OWNER. ANY REPAIR OR RECONSTRUCTION OF DAMAGED AREAS IN SURROUNDING PROPERTIES SHALL BE REPAIRED BY THE CONTRACTOR IMMEDIATELY. ALL COSTS FOR REPAIRS SHALL BE THE RESPONSIBILITY OF THE CONTRACTOR AND NO EXTRA COMPENSATION SHALL BE PROVIDED.

MATERIALS STORAGE/DEBRIS REMOVAL:
ALL MATERIALS EXCAVATED SHALL REMAIN THE PROPERTY OF THE OWNER AND SHALL BE STOCKPILED AT ON-SITE LOCATIONS AS SPECIFIED BY THE OWNER. MATERIALS SHALL BE STOCKPILED SEPARATELY AS TO USABLE (NON-ORGANIC) FILL STOCKPILES AND ORGANIC (MUCK) STOCKPILES IF MUCK IS ENCOUNTERED. CONTRACTOR SHALL BE RESPONSIBLE FOR THE REMOVAL OF ALL UNSUITABLE FILL MATERIALS FROM THE SITE.

COMPACTION: FILL MATERIALS PLACED UNDER PAVEMENT AND SIDEWALKS SHALL BE COMPACTED TO AT LEAST 98% MAXIMUM DENSITY AS SPECIFIED IN AASHTO T-180. ALL OTHER FILL AREAS ARE TO BE COMPACTED TO AT LEAST 95% MAXIMUM DENSITY AS SPECIFIED IN AASHTO T-180. FILL MATERIALS SHALL BE PLACED AND COMPACTED IN A MAXIMUM OF 12" LIFTS. THE CONTRACTOR SHALL PROVIDE THE ENGINEER AND OWNER WITH ALL (PASSING AND FAILING) TESTING RESULTS. RESULTS SHALL BE PROVIDED ON A TIMELY AND REGULAR BASIS PRIOR TO CONTRACTOR'S PAY REQUEST SUBMITTAL.

GRADING SHOWN ON THESE PLANS ARE PROVIDED TO THE CONTRACTOR TO EXPRESS THE GENERAL GRADING INTENT OF THE PROJECT. THE CONTRACTOR SHALL BE EXPECTED TO GRADE THE ENTIRE SITE TO PROVIDE POSITIVE DRAINAGE IN ALL AREAS THROUGHOUT THE SITE. SMOOTH TRANSITIONS SHALL BE PROVIDED BETWEEN CONTOURS OR SPOT ELEVATIONS AS SHOWN ON THE PLANS TO ACCOMPLISH THE GRADING INTENT. ALL SLOPES SHALL BE SODDED IMMEDIATELY AFTER FINAL GRADING HAS BEEN COMPLETED. CONTRACTOR SHALL NOTIFY OWNER AND ENGINEER PRIOR TO DEMOBILIZATION OF GRADING EQUIPMENT TO DETERMINE THAT THE GRADING INTENT HAS BEEN ACHIEVED.

THE CONTRACTOR SHALL BASE HIS BID ON HIS OWN ESTIMATE OF PAVEMENT QUANTITIES AND RELATED APPURTENANCES.

MATERIAL/CONSTRUCTION SPECIFICATIONS:
MATERIALS AND CONSTRUCTION METHODS FOR THE PAVEMENT CONSTRUCTION SHALL BE IN ACCORDANCE WITH THE FDOT STANDARD SPECIFICATIONS FOR ROAD AND BRIDGE CONSTRUCTION (LATEST EDITION).

PAVEMENT SECTION REQUIREMENTS:
SEE TYPICAL PAVEMENT DETAIL ON PLAN SHEET ON C-500.

SIDEWALKS:
SIDEWALKS ARE TO BE CONSTRUCTED IN THE AREAS AS SHOWN ON THE CONSTRUCTION PLANS. THE SIDEWALK SHALL BE CONSTRUCTED OF 4" THICK CONCRETE WITH A 28-DAY COMPRESSION STRENGTH OF 3000 PSI. JOINTS SHALL BE EITHER TOOLED OR SAWCUT AT EVERY 10' INTERVAL. HANDICAPPED RAMPS SHALL BE PROVIDED AT ALL INTERSECTIONS AND BE IN ACCORDANCE WITH STATE REGULATIONS FOR HANDICAP ACCESSIBILITY.

CURBING:
CURBING SHALL BE CONSTRUCTED WHERE NOTED ON THE CONSTRUCTION PLANS. CONCRETE FOR CURBS SHALL BE FLA. DEPARTMENT OF TRANSPORTATION CLASS "1" CONCRETE WITH A 28-DAY COMPRESSION STRENGTH OF 3000 PSI. ALL CURBS SHALL HAVE SAW CUT CONTRACTION JOINTS AND SHALL BE CONSTRUCTED AT INTERVALS NOT TO EXCEED 10'-0" ON CENTER. CONSTRUCTION OF CURBS SHALL BE IN CONFORMANCE WITH FDOT STANDARD SPECIFICATIONS FOR ROAD AND BRIDGE CONSTRUCTION (LATEST EDITION) SECTION 520 AND DETAILS PROVIDED ON THE CONSTRUCTION PLANS.

RESTORATION:
ALL DISTURBED AREAS SHALL BE FINISH GRADED WITH A SMOOTH TRANSITION INTO EXISTING GROUND. ALL SWALES SHALL BE STABILIZED IMMEDIATELY AFTER FINAL GRADING. ALL DISTURBED AREAS SHALL BE STABILIZED (SOD, GRASS & MULCH, ETC.) AFTER FINAL GRADING IN ACCORDANCE WITH THE CONSTRUCTION PLANS PRIOR TO FINAL INSPECTION. ALL GRASSING (SEED OR SOD) SHALL BE MAINTAINED BY THE CONTRACTOR UNTIL FINAL ACCEPTANCE BY THE OWNER/OPERATOR.

AS-BUILTS:
THE CONTRACTOR SHALL PROVIDE THE OWNER AND ENGINEER PAVEMENT AS-BUILTS. AS-BUILTS SHALL CONTAIN AT A MINIMUM, BUT NOT BE LIMITED TO, PAVEMENT WIDTHS, CROSS SLOPES AND DRAINAGE DIRECTIONS WITH HIGH POINTS DELINEATED.

TRENCH SAFETY:
THE CONTRACTOR SHALL RECOGNIZE AND ABIDE BY ALL OSHA EXCAVATION SAFETY STANDARDS, INCLUDING THE FLORIDA TRENCH SAFETY ACT (90-96, LAWS OF FLORIDA). ANY MATERIAL, CONSTRUCTION METHODS, OR MATERIAL COST TO COMPLY WITH THESE LAWS SHALL BE INCIDENTAL TO THE CONTRACT.

TRENCH OR EXCAVATION BOTTOM STABILIZATION MATERIAL:

A. SAND
SAND SHALL BE WELL GRADED, ORGANIC FREE, DURABLE, GRANULAR MATERIAL, AND SHALL PASS A NO. 4 SIEVE. NOT MORE THAN 15 PERCENT SHALL PASS A NO. 200 SIEVE.

B. PIT RUN GRAVEL
PIT RUN GRAVEL SHALL BE ORGANIC FREE AND SHALL PASS A 3/4-INCH SIEVE.

C. GRANULAR MATERIAL
GRANULAR MATERIAL SHALL BE WELL GRADED, ORGANIC AND SOIL FREE, DURABLE AGGREGATE AND SHALL PASS A 3/4-INCH SIEVE. NOT MORE THAN 15 PERCENT SHALL PASS A NO. 200 SIEVE.

THE FOLLOWING DESIGN GUIDELINES (LATEST EDITIONS) WERE UTILIZED IN GENERATING THE DESIGN PLANS

- A. FLORIDA BUILDING CODE (FBC)
B. STATE REQUIREMENTS FOR EDUCATIONAL FACILITIES (SREF)
C. VOLUSIA COUNTY SCHOOLS DESIGN GUIDELINES

CONTRACTOR SHALL REFERENCE AND COMPLY WITH THESE GUIDELINE FOR MATERIAL AND CONSTRUCTION METHOD REQUIREMENTS.



ALLEN C. LANE, P.E.
FL. REG. No. 60144

[illegible]

UNIVERSITY HIGH SCHOOL
EXTEND PARENT LOOP
VCS Project NO. 2548185
1000 RHODE ISLAND AVE., ORANGE CITY
VOLUSIA COUNTY, FLORIDA 32763

ARCHENGR OF RECORD

Allen C. Lane, P.E.


DESIGNED BY BCB	DRAWN BY ZA
ISSUE DATE 02.07.25	AE PROJECT NUMBER 2501359


SHEET TITLE

GENERAL NOTES

DRAWING NO.

G002

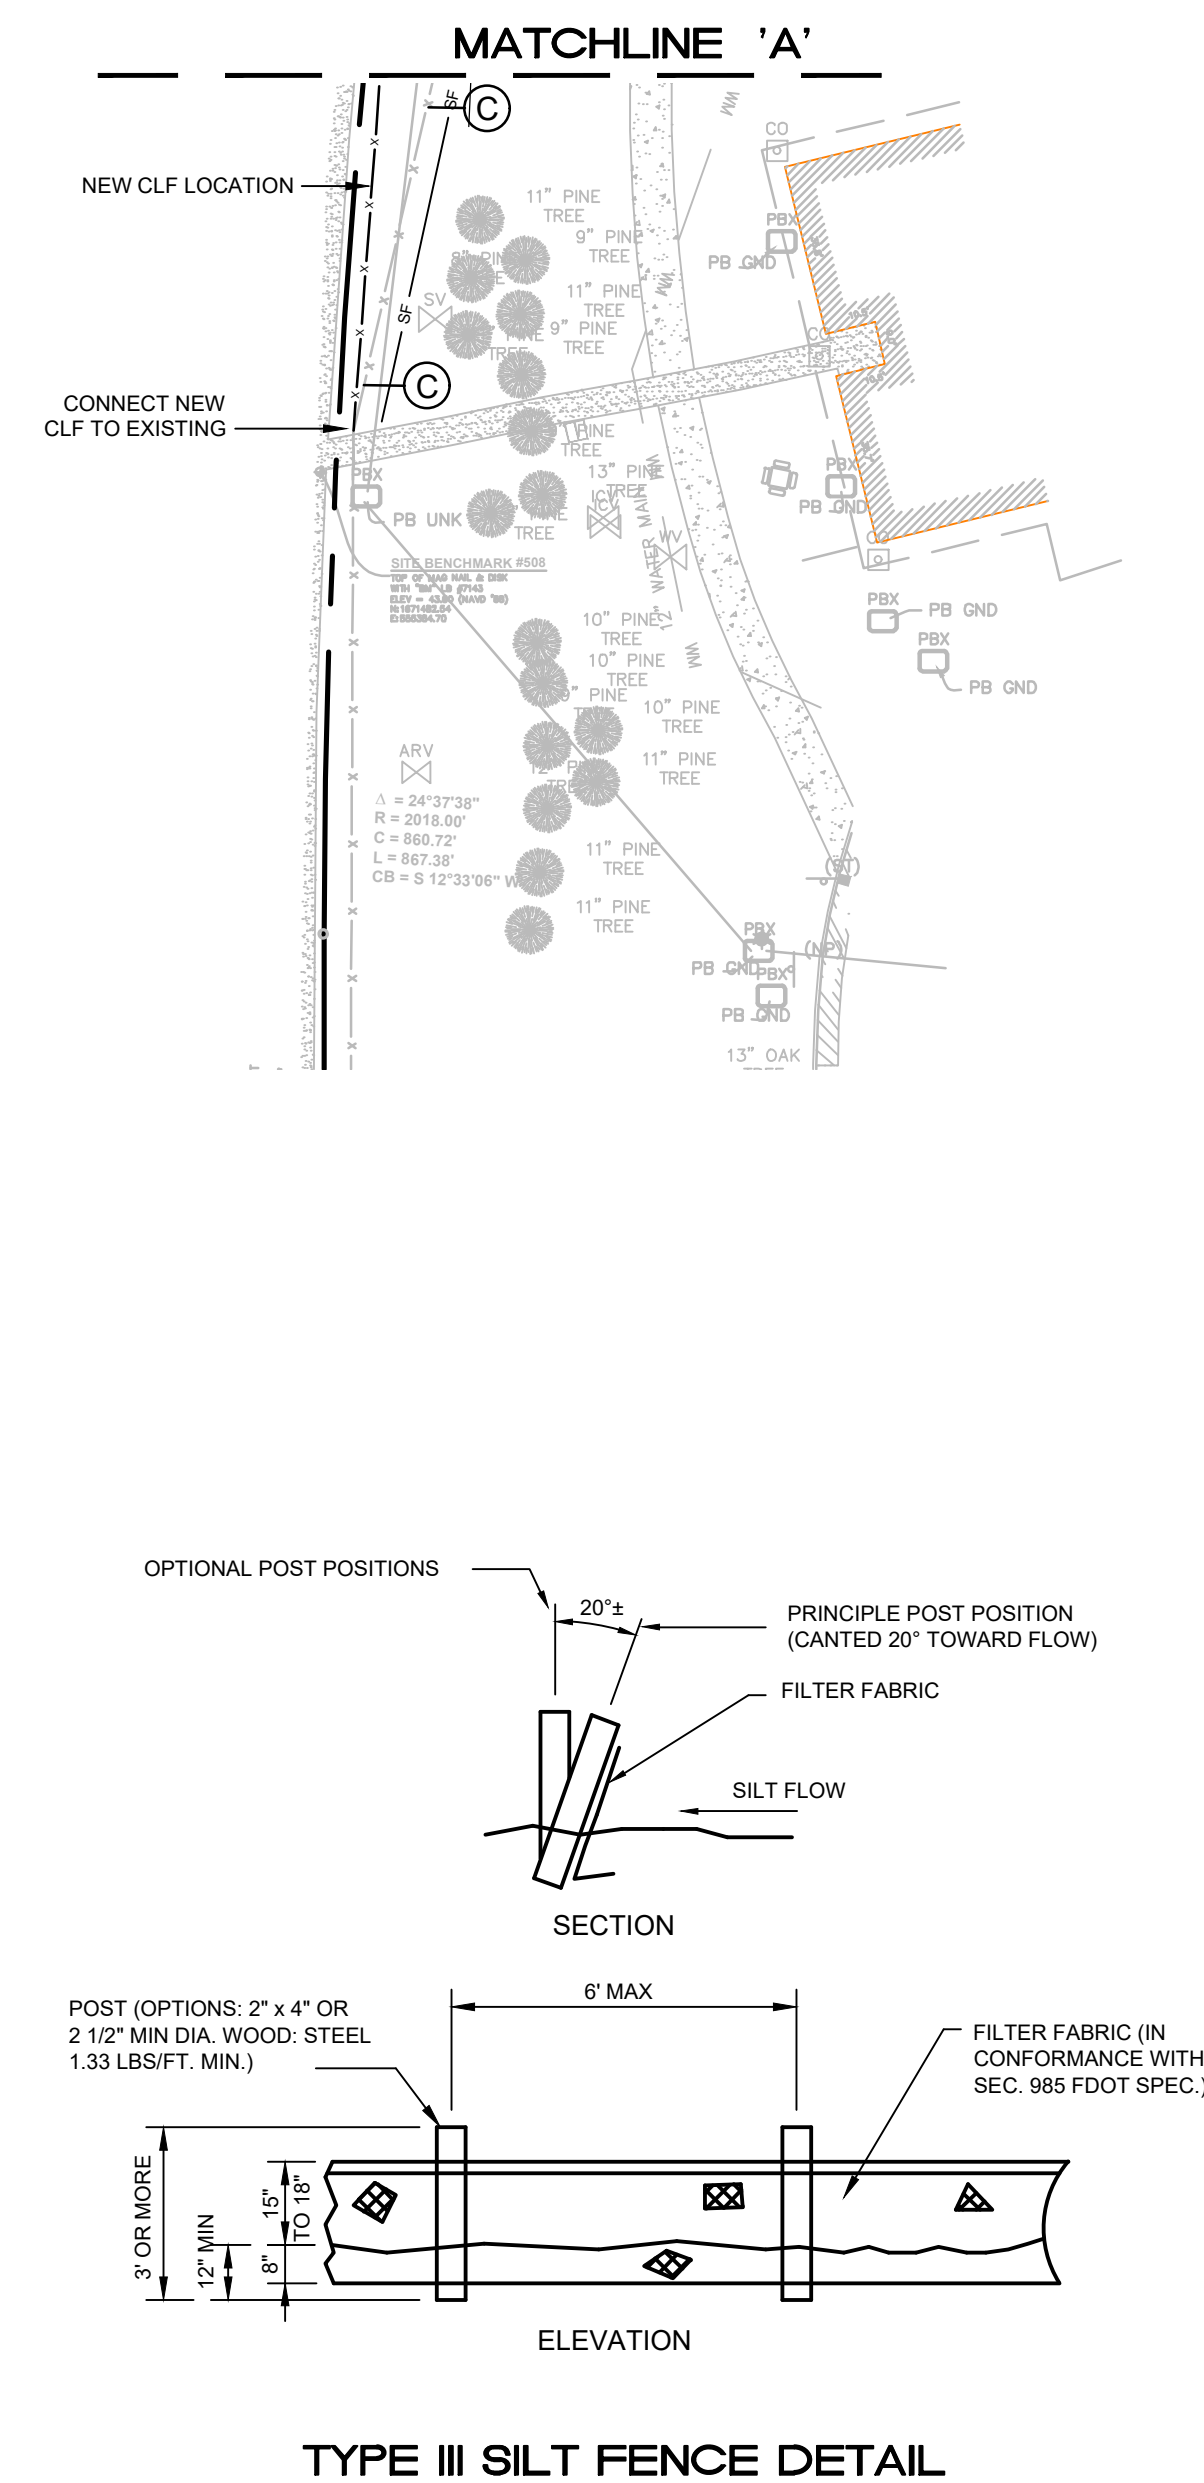[illegible]

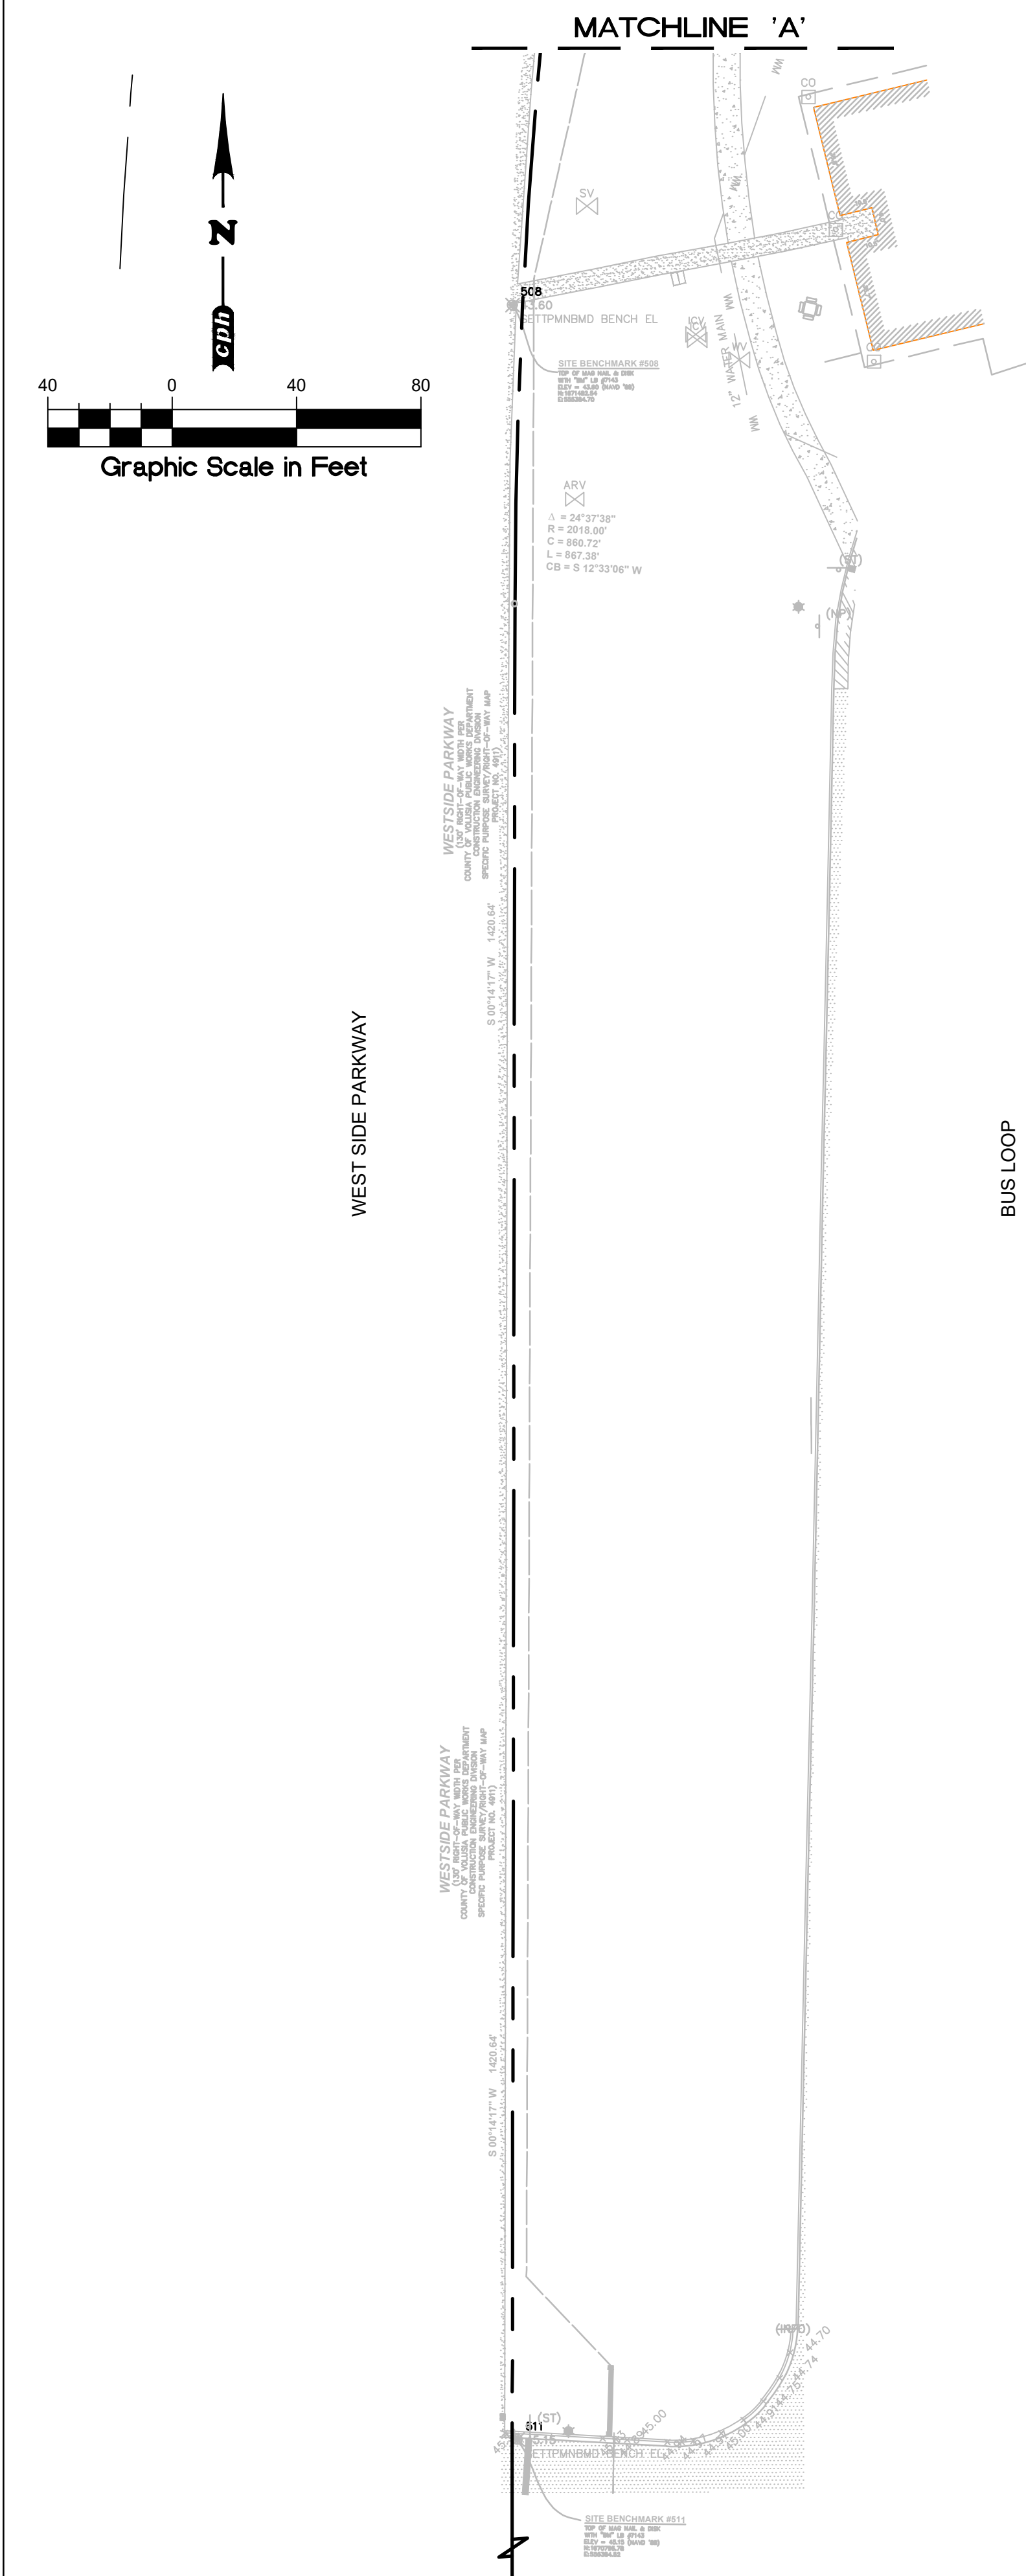

ALLEN C. LANE, P.E.
FL. REG. No. 60144

REVISIONS

DOCUMENT HISTORY

1/6/2026

CONFORMED SET

UNIVERSITY HIGH SCHOOL
EXTEND PARENT LOOP
VCS Project NO. 2548185
1000 RHODE ISLAND AVE., ORANGE CITY
VOLUSIA COUNTY, FLORIDA 32763

CHANGES OF RECORD

Allen C. Lane, P.E.

DESIGNED BY
BCB

DRAWN BY
ZA


SUE DATE

PROJECT NUMBER

DIMENSION, AND STRIPING PLAN

RAYING NO.

C101

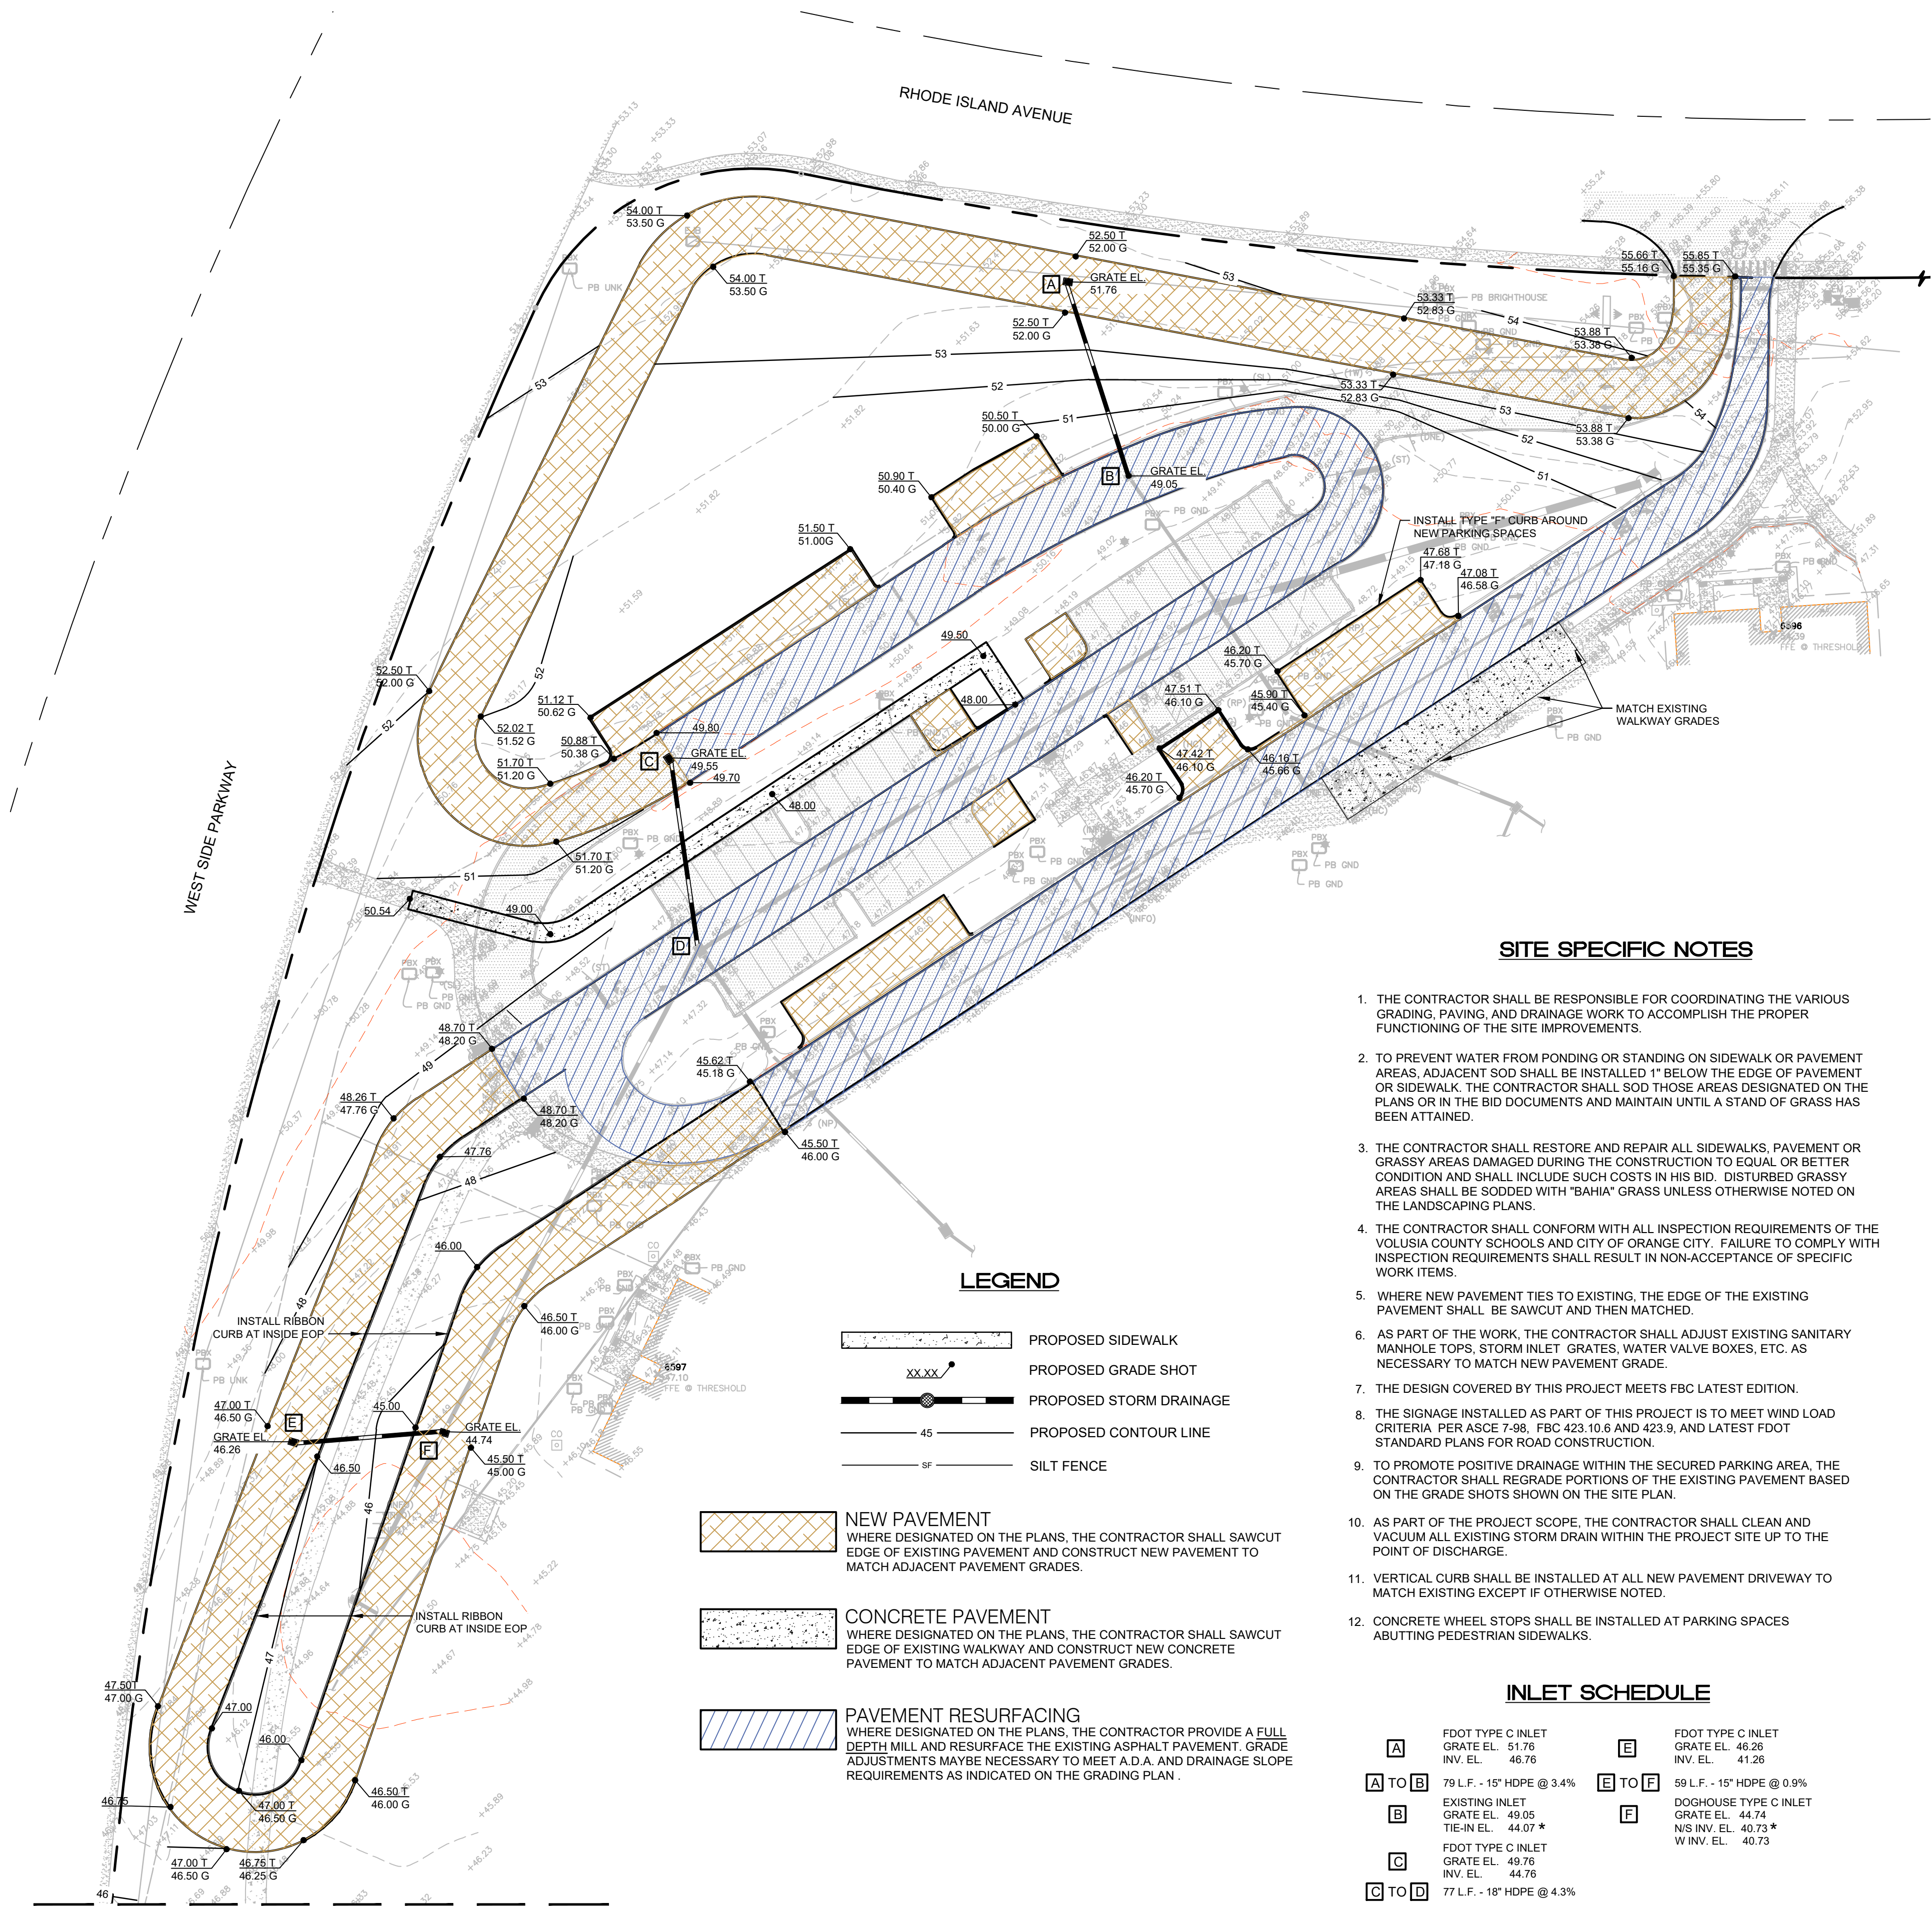


SITE SPECIFIC NOTES

1. THE CONTRACTOR SHALL BE RESPONSIBLE FOR COORDINATING THE VARIOUS GRADING, PAVING, AND DRAINAGE WORK TO ACCOMPLISH THE PROPER FUNCTIONING OF THE SITE IMPROVEMENTS.
2. TO PREVENT WATER FROM PONDING OR STANDING ON SIDEWALK OR PAVEMENT AREAS, ADJACENT SOD SHALL BE INSTALLED 1" BELOW THE EDGE OF PAVEMENT OR SIDEWALK. THE CONTRACTOR SHALL SOD THOSE AREAS DESIGNATED ON THE PLANS OR IN THE BID DOCUMENTS AND MAINTAIN UNTIL A STAND OF GRASS HAS BEEN ATTAINED.
3. THE CONTRACTOR SHALL RESTORE AND REPAIR ALL SIDEWALKS, PAVEMENT OR GRASSY AREAS DAMAGED DURING THE CONSTRUCTION TO EQUAL OR BETTER CONDITION AND SHALL INCLUDE SUCH COSTS IN HIS BID. DISTURBED GRASSY AREAS SHALL BE SODDED WITH "BAHIA" GRASS UNLESS OTHERWISE NOTED ON THE LANDSCAPING PLANS.
4. THE CONTRACTOR SHALL CONFORM WITH ALL INSPECTION REQUIREMENTS OF THE VOLUSIA COUNTY SCHOOLS AND CITY OF ORANGE CITY. FAILURE TO COMPLY WITH INSPECTION REQUIREMENTS SHALL RESULT IN NON-ACCEPTANCE OF SPECIFIC WORK ITEMS.
5. WHERE NEW PAVEMENT TIES TO EXISTING, THE EDGE OF THE EXISTING PAVEMENT SHALL BE SAWCUT AND THEN MATCHED.
6. AS PART OF THE WORK, THE CONTRACTOR SHALL ADJUST EXISTING SANITARY MANHOLE TOPS, STORM INLET GRATES, WATER VALVE BOXES, ETC. AS NECESSARY TO MATCH NEW PAVEMENT GRADE.
7. THE DESIGN COVERED BY THIS PROJECT MEETS FBC LATEST EDITION.
8. THE SIGNAGE INSTALLED AS PART OF THIS PROJECT IS TO MEET WIND LOAD CRITERIA PER ASCE 7-98, FBC 423.10.6 AND 423.9, AND LATEST FDOT STANDARD PLANS FOR ROAD CONSTRUCTION.
9. TO PROMOTE POSITIVE DRAINAGE WITHIN THE SECURED PARKING AREA, THE CONTRACTOR SHALL REGRADE PORTIONS OF THE EXISTING PAVEMENT BASED ON THE GRADE SHOTS SHOWN ON THE SITE PLAN.
10. AS PART OF THE PROJECT SCOPE, THE CONTRACTOR SHALL CLEAN AND VACUUM ALL EXISTING STORM DRAIN WITHIN THE PROJECT SITE UP TO THE POINT OF DISCHARGE.
11. VERTICAL CURB SHALL BE INSTALLED AT ALL NEW PAVEMENT DRIVEWAY TO MATCH EXISTING EXCEPT IF OTHERWISE NOTED.
12. CONCRETE WHEEL STOPS SHALL BE INSTALLED AT PARKING SPACES ABUTTING PEDESTRIAN SIDEWALKS.

INLET SCHEDULE

A	FDOT TYPE C INLET GRATE EL. 51.76 INV. EL. 46.76	E	FDOT TYPE C INLET GRATE EL. 48.26 INV. EL. 41.26
A TO B	79' L.F. - 15" HDPE @ 3.4%	E TO F	59' L.F. - 15" HDPE @ 0.9%
B	EXISTING INLET GRATE EL. 49.05 TIE-IN EL. 44.07 *	F	DOGHOUSE TYPE C INLET GRATE EL. 44.74 N/S INV. EL. 40.73 *
C	FDOT TYPE C INLET GRATE EL. 49.76 INV. EL. 44.76		W INV. EL. 40.73
C TO D	77' L.F. - 18" HDPE @ 4.3%		
D	EXISTING INLET GRATE EL. 46.46 TIE-IN EL. 41.46 *		

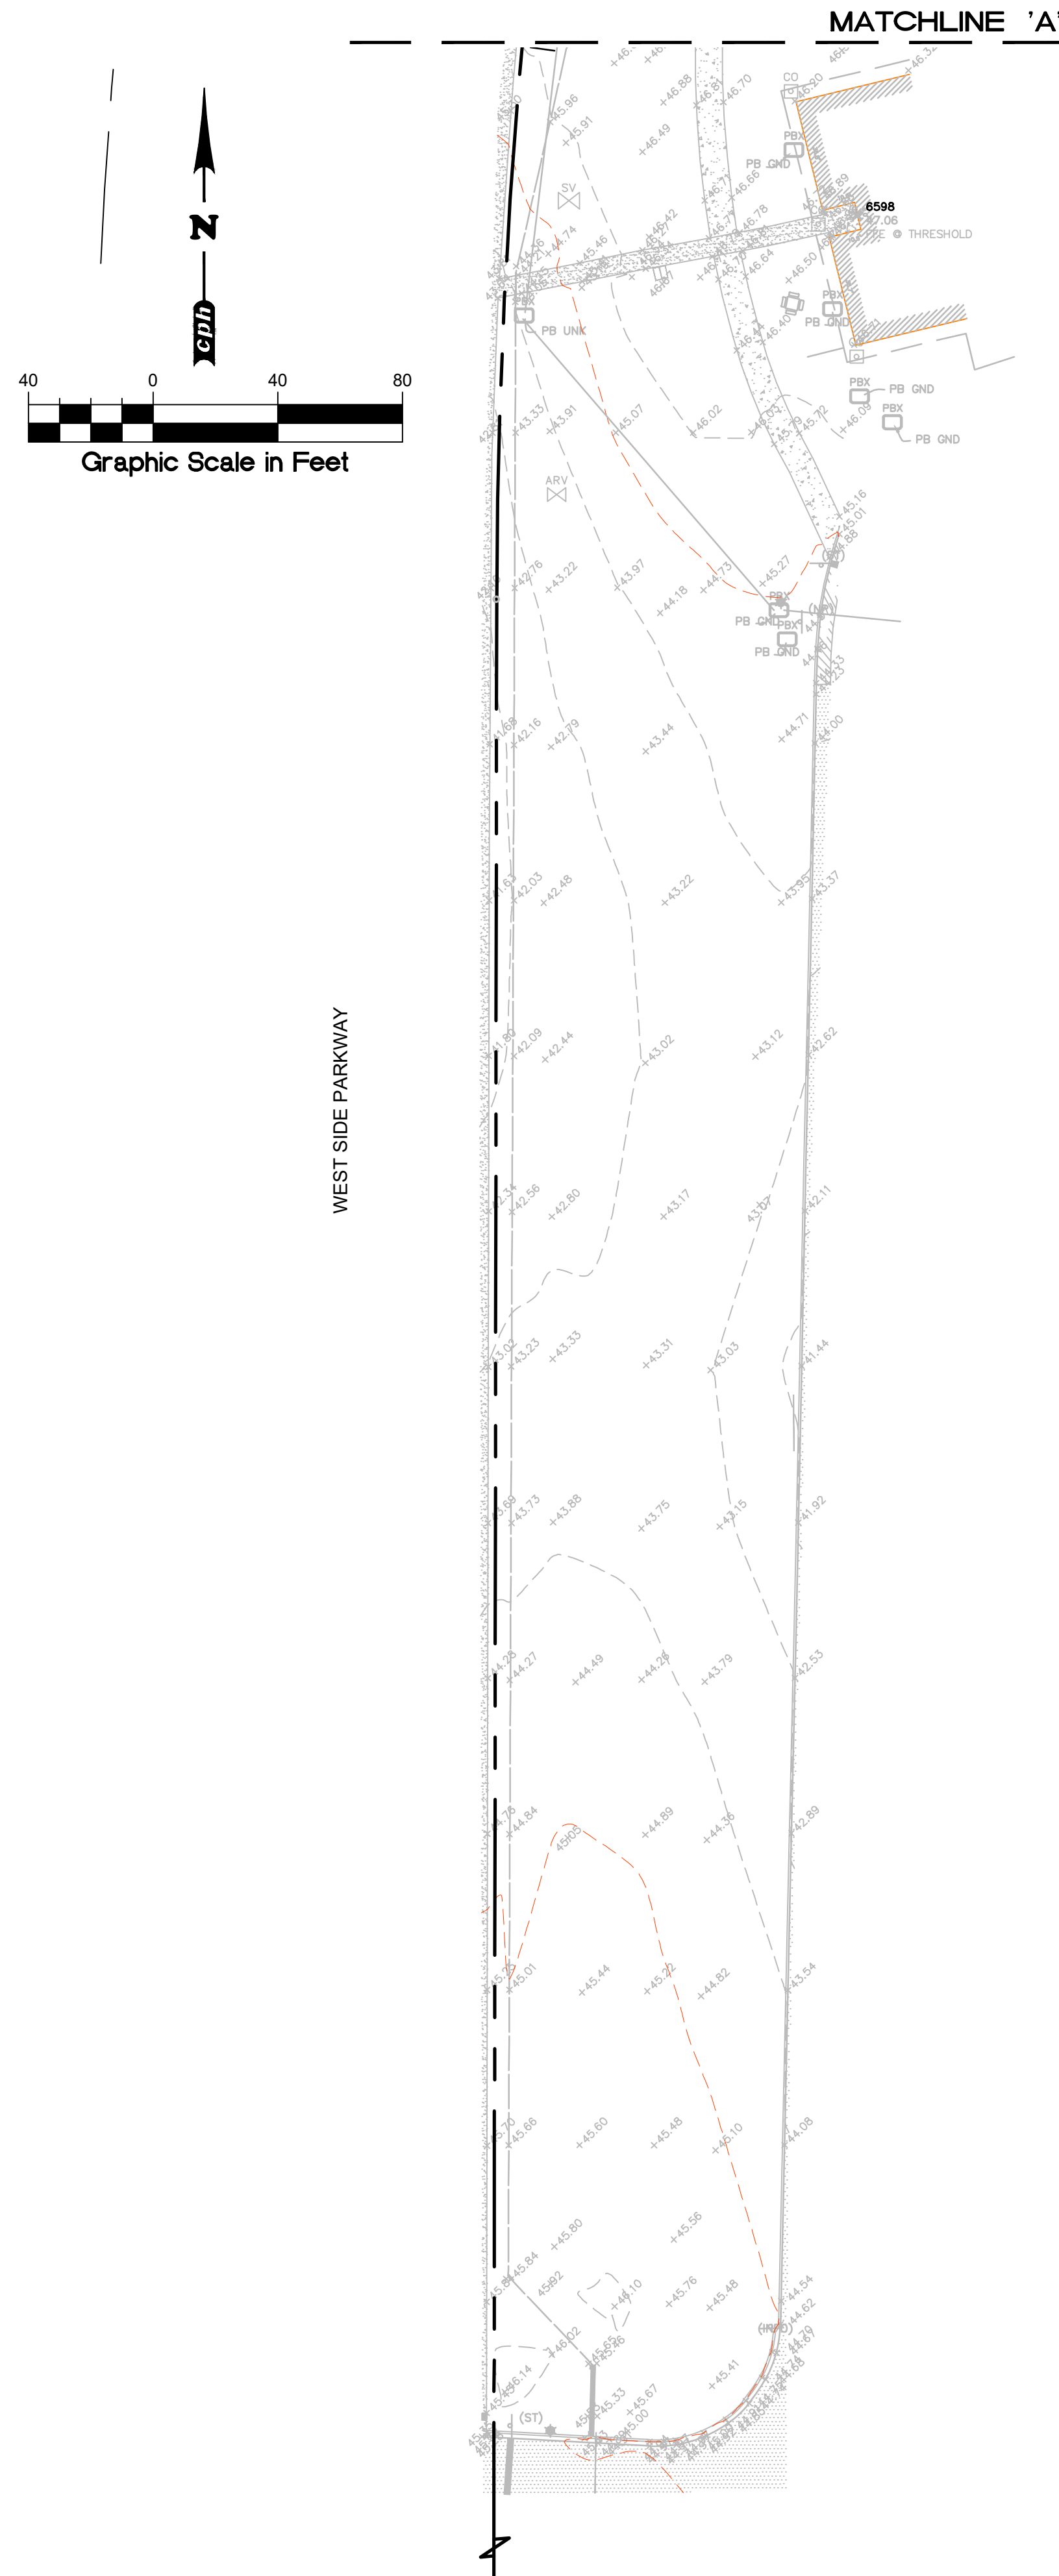

cph
www.cphcorp.com
**Building Better
Communities Together**
1117 East Robinson Street
Orlando, FL 32801
Ph: 407.425.0452
Plans Prepared By
CPH, LLC
A Full Service A & E Firm
State of Florida License:
Engineer No. 3215
Surveyor No. LB7143
Architect No. AAS0000926
Landscape No. LC000238

ALLEN C. LANE, P.E.
FL REG. No. 60144

REVISIONS

DOCUMENT HISTORY	CONFORMED SET
1/6/2026	

**UNIVERSITY HIGH SCHOOL
EXTEND PARENT LOOP
VCS Project NO. 2548185
1000 RHODE ISLAND AVE., ORANGE CITY
VOLUSIA COUNTY, FLORIDA 32763**

Allen C. Lane, P.E.

DESIGNED BY BCB	DRAWN BY ZA
ISSUE DATE 02.07.25	AE PROJECT NUMBER 2501359

**GRADING AND
DRAINAGE PLAN**

DRAWING NO.

C102


GENERAL NOTES

1. ALL WORK SHALL COMPLY WITH CODES AND LOCAL STANDARDS.
2. CONTRACTOR SHALL CALL ALL UTILITIES TO MARK EXISTING UNDERGROUND LINES PRIOR TO START OF ANY AND ALL SITE WORK.
3. THE DRAWINGS ARE DIAGRAMMATIC AND THE OMISSION OF AN ITEM NECESSARY FOR THE PROPER FUNCTIONING OF THE SYSTEM DOES NOT RELIEVE THE CONTRACTOR FROM FURNISHING AND INSTALLING THAT ITEM.
4. NOTIFY CIVIL/ ENGINEER OF ANY IN FIELD CONFLICTS WITH DRAWINGS PRIOR TO PURCHASING EQUIPMENT AND PRIOR TO ANY DIGGING.
5. UNDERGROUND CONDUIT IS TO BE A MINIMUM OF 24" BELOW GRADE. ALL EXISTING UTILITIES SHALL GOVERN AND NEW WORK IS TO COORDINATE AND AVOID UTILITY.
6. METAL SURFACES ARE TO BE GROUNDED.
7. SHADED LINE-TYPE INDICATES EXISTING AND HIGHLIGHTED LINE

ABBREVIATIONS			
MARK	DESCRIPTION		
ABV	ABOVE	KW	KILOWATT
AF	TYPE INDICATES NEW WORK TO BE DONE.	KVA	KILOVOLT-AMPERE
AF	ABOVE FINISHED FLOOR	KO	KNOCKOUT
ACL	CROSS THE LINE	LED	LIGHT EMITTING DIODE
AC	ALTERNATING CURRENT	LTG	LIGHTING
A	AMPERE	LV	LOW VOLTAGE
AMP	AMPERE	MFR	MANUFACTURER
AIC	AMPERES INTERRUPTING CAPACITY	MTD	MOUNTED
BR	BRANCH	NEC	NATIONAL ELECTRICAL CODE
BKR	BREAKER	NC	NORMALLY CLOSED
CAB	CABINET	NO	NORMALLY OPENED
C.B.	CIRCUIT BREAKER	NIC	NOT IN CONTRACT
CCT	CIRCUIT	NTS	NOT TO SCALE
C	CONDUIT	OCPD	OVERCURRENT PROTECTION DEVICE
CONT	CONTINUOUS	PNL	PANEL
CP	CONTROL PANEL	PH	PHASE
Cu	COPPER	PWR	POWER
CT	CURRENT TRANSFORMER	PB	PULL BOX
Hz	HERTZ (CYCLES/SECOND)	RT	RAINTIGHT
DED	DEDICATED CIRCUIT	RECEP	RECEPTACLE
DS	DISCONNECT SWITCH	RC	REMOTE CONTROL
ELEC	ELECTRIC	R	RELOCATED
ETR	EXISTING TO REMAIN	SEC	SECONDARY
EQ	EQUIPMENT	SP	SINGLE POLE
EX	EXISTING	SPD	SURGE PROTECTION DEVICE
FUT	FUTURE	SPEC	SPECIFICATION
GRD, G	GROUND	SS	STAINLESS STEEL
GFI	GROUND FAULT INTERRUPTER	UNO	UNLESS NOTED OTHERWISE
HV	HIGH VOLTAGE	V	VOLT
IC	INTERRUPTING CAPACITY	VA	VOLT-AMPERE
		WT	WATERTIGHT
		W	WATT
		WP	WEATHERPROOF

SYMBOL	DESCRIPTION
	EXISTING LUMINAIRE AND POLE - SQUARES INDICATE NUMBER OF LUMINAIRES
	NEW LUMINAIRE AND POLE - SQUARES INDICATE NUMBER OF LUMINAIRES
	NEW LUMINAIRE ON EXISTING POLE-SQUARES INDICATE NUMBER OF LUMINAIRES
	IN-GRADE JUNCTION BOX
	METAL JUNCTION BOX
	CONDUIT - SOLID LINE INDICATES EQUIPMENT ON COMMON CIRCUIT AND/OR CONTROLLED BY COMMON SWITCH. EACH CIRCUIT SHALL CONSIST OF A PHASE CONDUCTOR, NEUTRAL AND GROUND. ELECTRICAL CONTRACTOR SHALL PROVIDE NECESSARY CONNECTIONS FOR A FULLY OPERABLE SYSTEM.
	UNDERGROUND CONDUIT AND CONDUCTOR.
	CIRCUIT HOMERUN.

ELECTRICAL DRAWING INDEX	
SHEET	DESCRIPTION
E001	ELECTRICAL GENERAL NOTES
E100	ELECTRICAL DEMOLITION SITE PLAN
E101	ELECTRICAL CONSTRUCTION PLAN
E200	PHOTOMETRIC SITE PLAN
E300	ELECTRICAL SCHEDULES & DETAILS

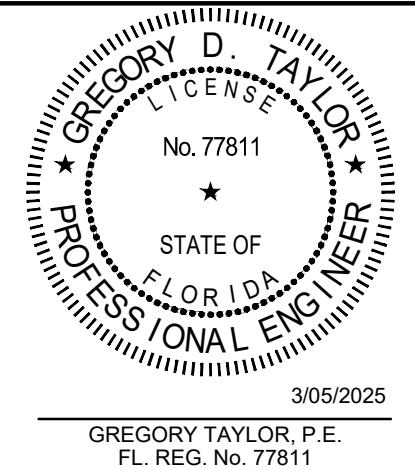[illegible]

UNIVERSITY HIGH SCHOOL
EXTEND PARENT LOOP
VCS Project NO. 2548185
1000 W. RHODE ISLAND AVE., ORANGE CITY FL 32763

Gregory D. Taylor, P.E.


DESIGNED BY GT	DRAWN BY EP
ISSUE DATE JAN. 2025	AE PROJECT NUMBER 2400653
SHEET TITLE ELECTRICAL GENERAL NOTES	
DRAWING NO.	

DRAWING NO.


E001

1000 W. RHODE ISLAND AVE., ORANGE CITY FL 32763

This item has been electronically signed and sealed by Gregory D. Taylor on the date adjacent to the seal using a SHA authentication code. printed.

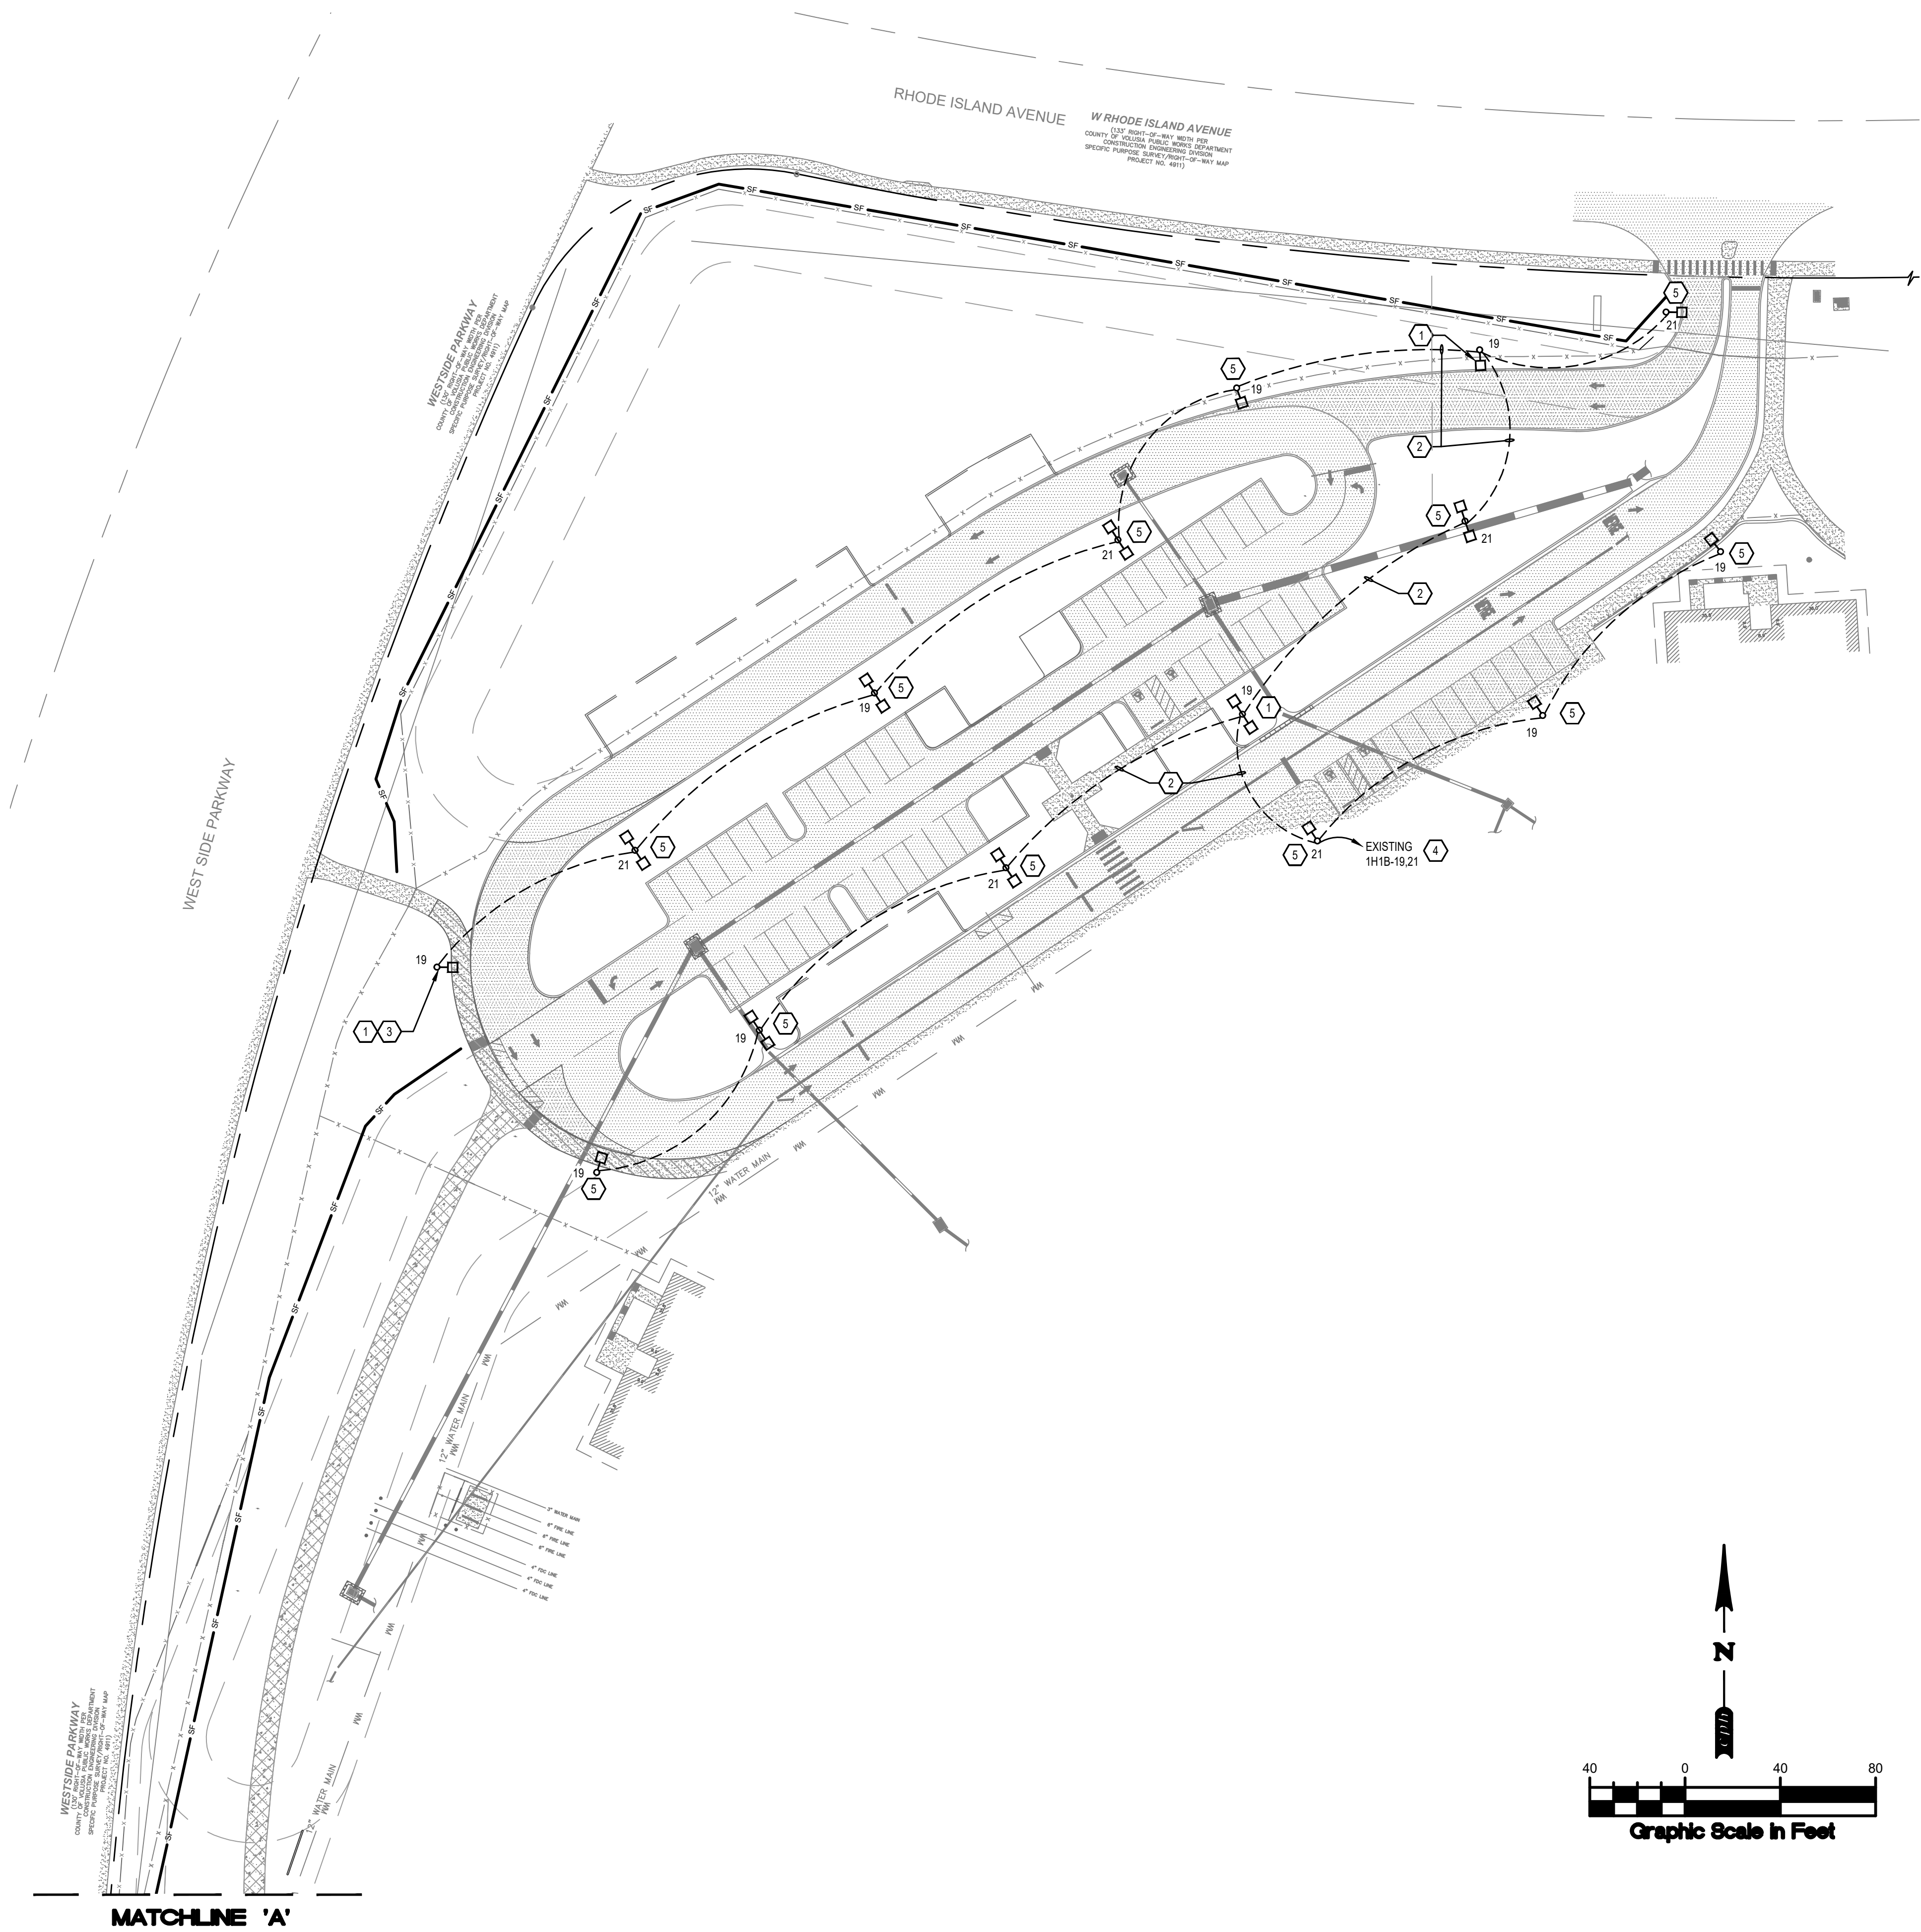

MATCHLINE 'A'

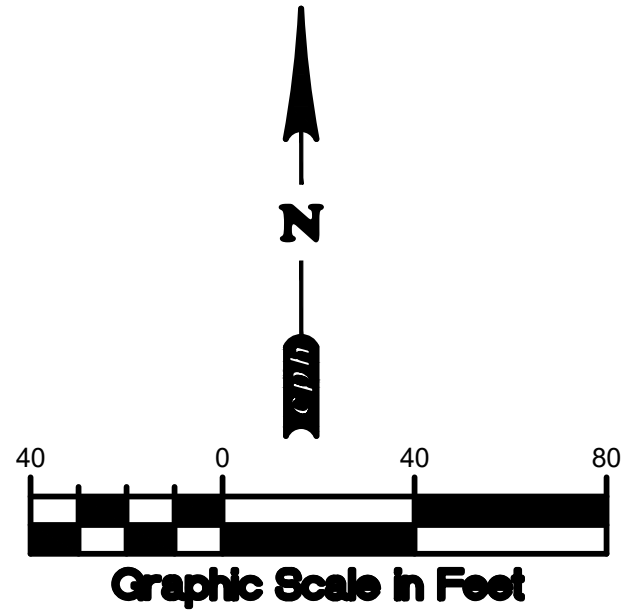

DEMOLITION GENERAL NOTES

1. DEVICES SHOWN ON THE DEMO PLAN ARE EXISTING. REFER TO SYMBOL LEGEND FOR DEVICE DESCRIPTION.
2. EXISTING CONDITIONS SHOWN ON THIS DRAWING ARE TAKEN FROM ORIGINAL DRAWINGS AND FIELD INVESTIGATION. ALL EXISTING CONDITIONS MUST BE VERIFIED PRIOR TO BID. FIELD CONDITIONS SHALL GOVERN.
3. THE DEMOLITION PLAN IS NOT INCLUSIVE OF ALL ELECTRICAL DEVICES WITHIN THE PROJECT AREA. IT IS INTENDED TO PROVIDE THE CONTRACTOR WITH A GENERAL KNOWLEDGE OF THE EXISTING CONDITIONS WITHIN THE PROJECT AREA. ANY DISCREPANCIES OR CONDITIONS NOT SHOWN ON THIS PLAN SHALL BE BROUGHT TO THE ATTENTION OF THE ENGINEER. THE CONTRACTOR IS RESPONSIBLE FOR ALL REQUIRED DEMOLITION WHETHER SHOWN ON THE PLANS OR NOT.
4. EXISTING UNDERGROUND CONDUITS SERVING LIGHT POLES, THAT RUN THROUGH THE PROJECT AREA SHALL REMAIN ACTIVE DURING CONSTRUCTION. IT IS THE CONTRACTOR'S RESPONSIBILITY TO INSURE THAT ALL CONDUITS, NEW OR EXISTING, WITHIN THE PROJECT AREA ARE PROPERLY SUPPORTED AND PROVIDED W/ BONDING BUSHINGS IN ACCORDANCE WITH THE NATIONAL ELECTRIC CODE.
5. ITEMS REMOVED UNDER THIS PROJECT SHALL BE DISPOSED OF OR TURNED OVER TO THE OWNER AT THE OWNER'S DISCRETION.
6. THIS CONTRACTOR SHALL PROVIDE ELECTRICAL FOR PHASING WORK AS REQUIRED OR DIRECTED BY THE CIVIL ENGINEER. TEMPORARY ELECTRICAL SERVICES (POWER, LIGHTING, ETC.)
7. EXISTING PANEL AND CIRCUITING SHALL BE TRACED AND VERIFIED BEFORE START OF WORK.
8. CONTRACTOR IS RESPONSIBLE FOR PROVIDING UTILITY LOCATES BEFORE COMMENCING WORK. COORDINATE ELECTRICAL CONDUIT ROUTING AND EQUIPMNET WITH OTHER UTILITIES.

KEY NOTES

- 1 REMOVE DIRECT-BURIED LIGHT POLE WITH PULL BOX AND LUMINAIRE. DEMO POLE WITH PULL BOX AND TURN LUMINAIRE OVER TO OWNER
- 2 REMOVE CONDUCTORS. REMOVE CONDUIT BELOW PROPOSED ROADWAY, CAP AND ABANDON CONDUIT BELOW GRADE IN LANDSCAPE AREAS.
- 3 REPLACE LIGHT POLE WITH 13'X24' IN-GRADE JUNCTION BOX AND RECONNECT CONDUCTORS - SEE CONSTRUCTION PLAN KEYNOTE 3.
- 4 EXISTING MULTIWIRE BRANCH CIRCUIT VIA EXISTING LIGHTING CONTACTORS SUCH THAT ONE CIRCUIT IS ON FROM DUSK TO DAWN AND THE OTHER CIRCUIT IS ON AT DUSK AND TURNS OFF AT A PRESET TIME. SEE CONSTRUCTION PLAN KEYNOTE 4.
- 5 REMOVE LUMINAIRE(S) AND TURN OVER TO OWNER. POLE TO REMAIN FOR INSTALLATION OF NEW LUMINAIRE(S).




cph
www.cphcorp.com
Building Better Communities Together
1117 East Robinson Street
Orlando, FL 32801
Ph: 407.425.0452
Plans Prepared By
CPH, LLC
A Full Service A & E
State of Florida License:
Engineer No. 3215
Surveyor No. 187143
Architect No. AA25000926
Landscape No. LC000298

GREGORY D. TAYLOR
No. 77811
STATE OF FLORIDA
PROFESSIONAL ENGINEER
3/05/2025
GREGORY TAYLOR, P.E.
FL REG. No. 77811

REVISIONS	DOCUMENT HISTORY	
	DATE	DESCRIPTION
	1/8/2026	CONFORMED SET

UNIVERSITY HIGH SCHOOL
EXTEND PARENT LOOP
VCS Project NO. 2548185
1000 W. RHODE ISLAND AVE., ORANGE CITY FL 32763

ARCHVENER OF RECORD Gregory D. Taylor, P.E.	
DESIGNED BY GT	DRAWN BY EP
ISSUE DATE JAN. 2025	AE PROJECT NUMBER 2400653
SHEET TITLE ELECTRICAL DEMOLITION PLAN	
DRAWING NO. E100	

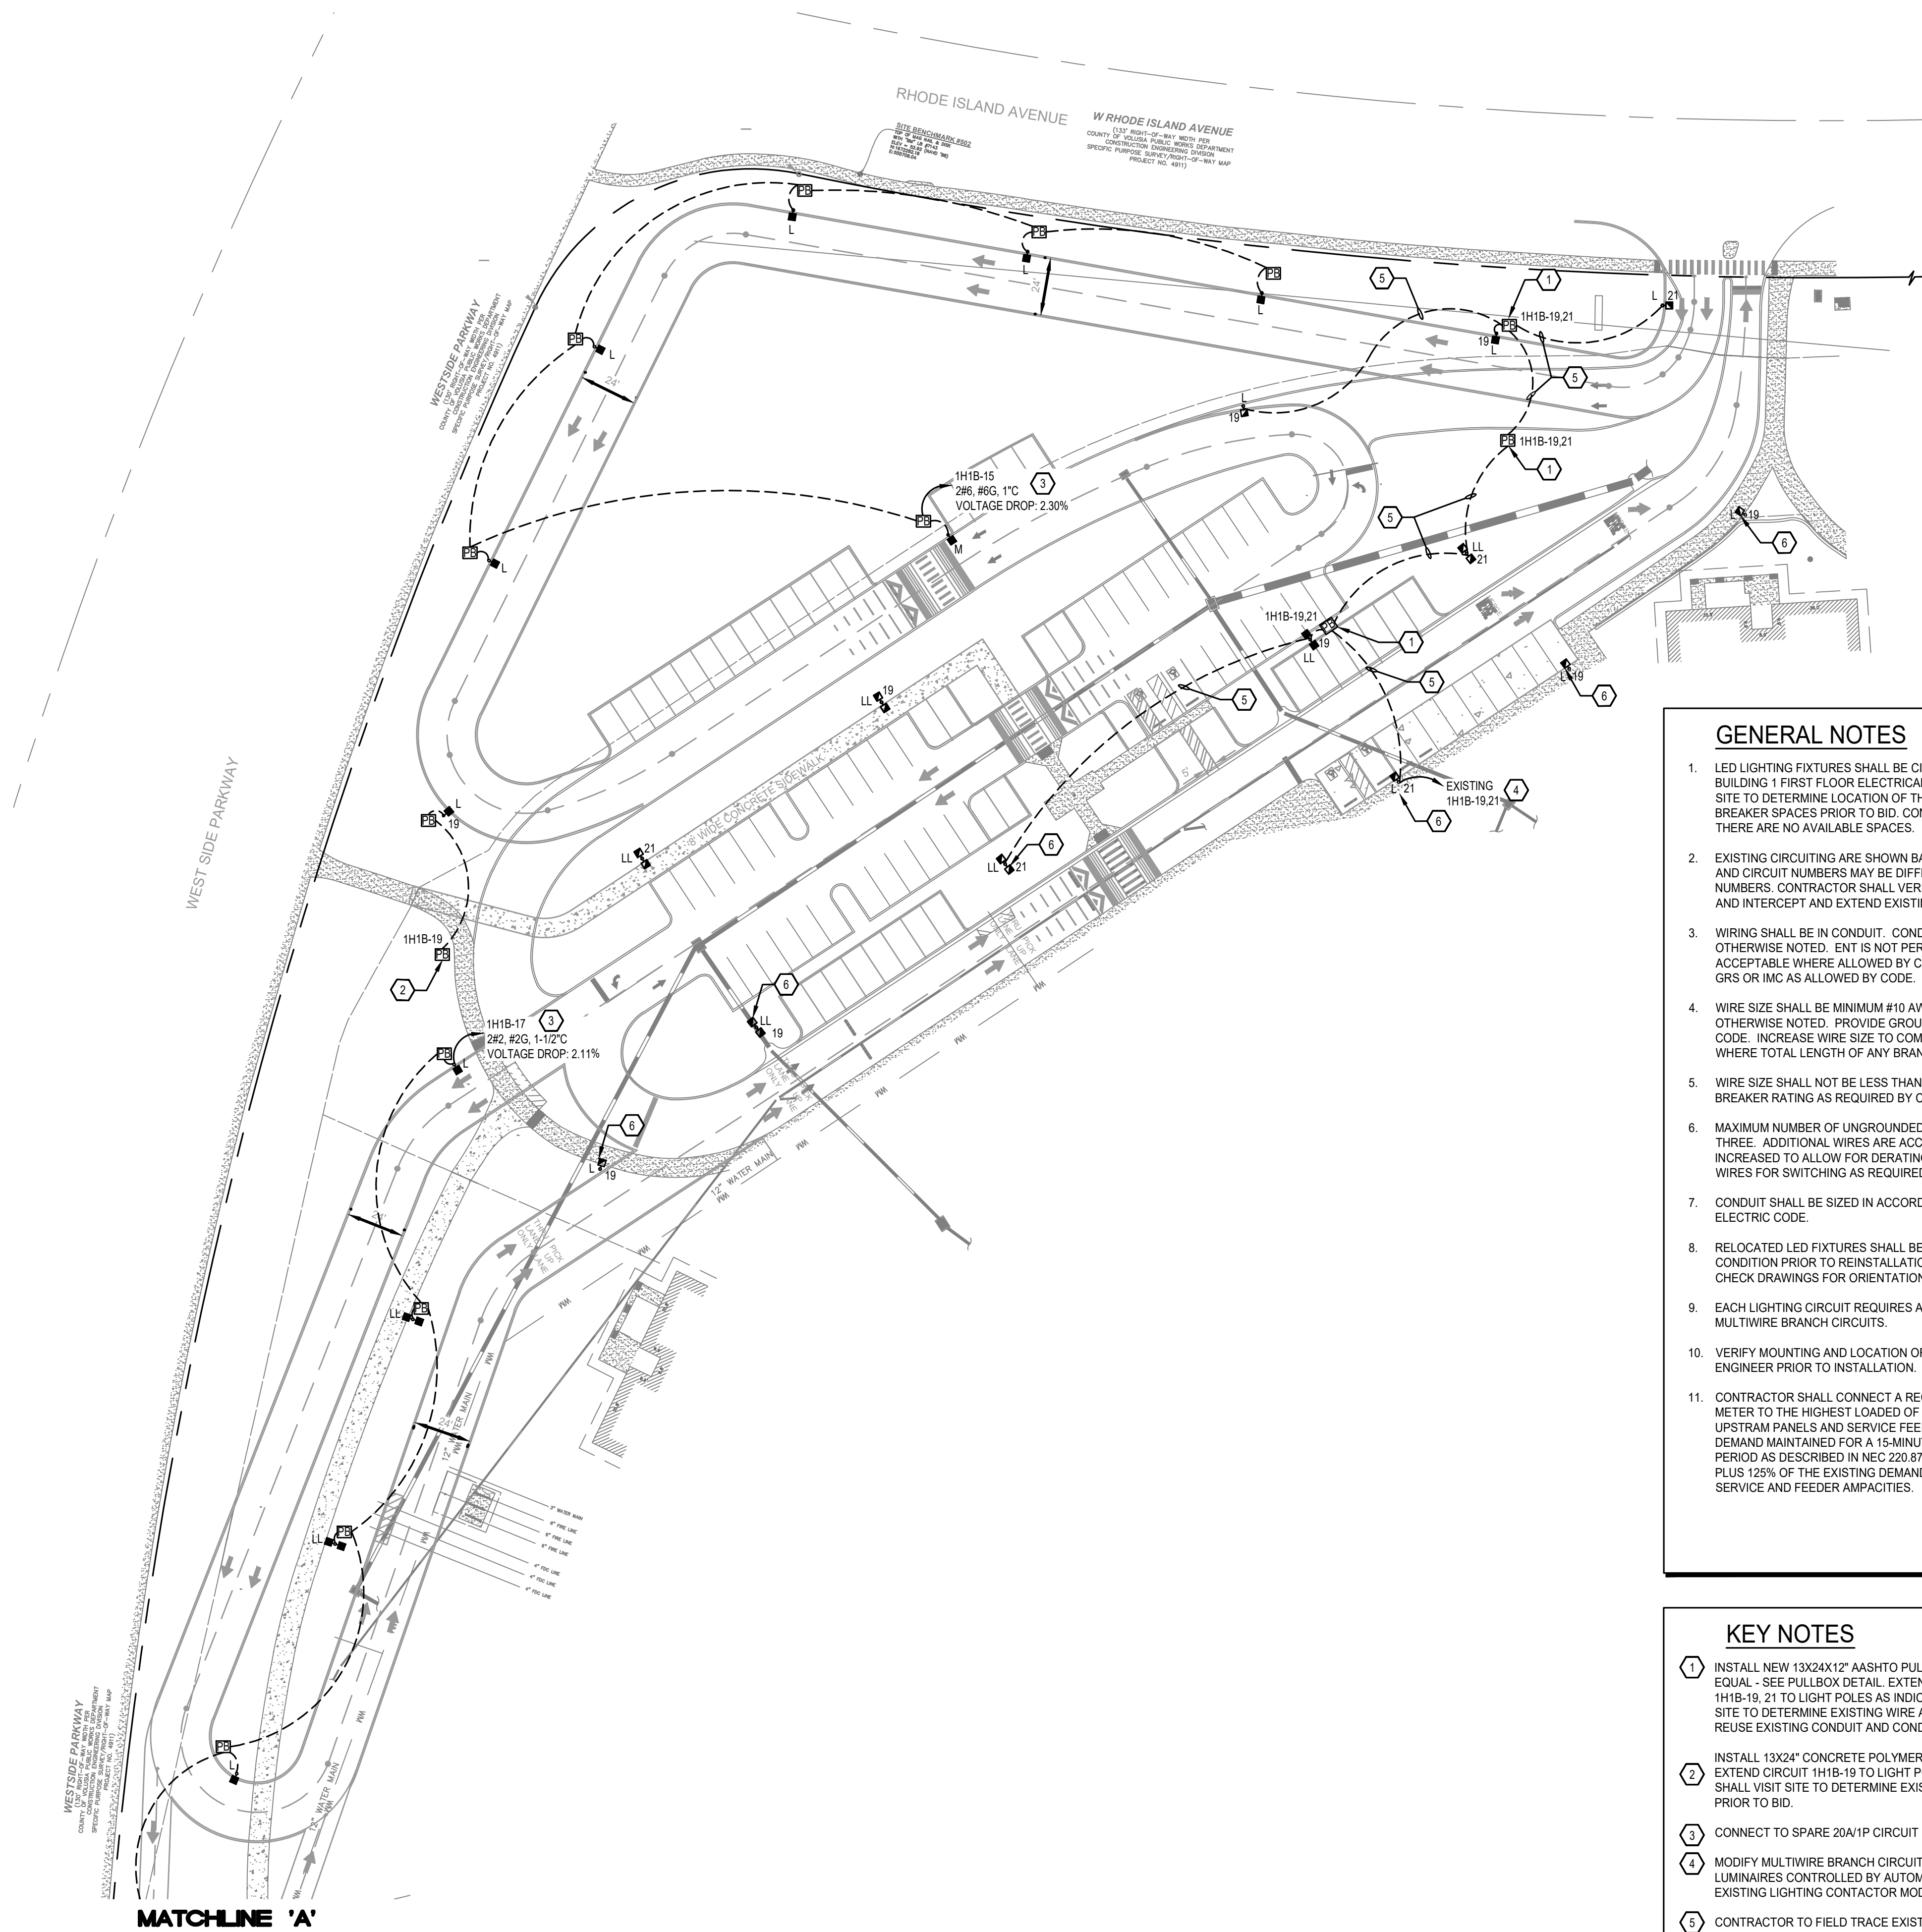


GENERAL NOTES

- LED LIGHTING FIXTURES SHALL BE CIRCUITED TO PANEL '1H1B' IN BUILDING 1 FIRST FLOOR ELECTRICAL ROOM. CONTRACTOR SHALL VISIT SITE TO DETERMINE LOCATION OF THE PANEL AND AVAILABLE CIRCUIT BREAKER SPACES PRIOR TO BID. CONTACT ENGINEER OF RECORD IF THERE ARE NO AVAILABLE SPACES.
- EXISTING CIRCUITING ARE SHOWN BASED ON AS-BUILTS AND ROUTING AND CIRCUIT NUMBERS MAY BE DIFFERENT THAN EXISTING CIRCUIT NUMBERS. CONTRACTOR SHALL VERIFY ACTUAL CIRCUITS IN THE FIELD AND INTERCEPT AND EXTEND EXISTING CONDUIT AND ROUTING.
- WIRING SHALL BE IN CONDUIT. CONDUIT SIZE IS 3/4" MINIMUM UNLESS OTHERWISE NOTED. ENT IS NOT PERMITTED. SCHEDULE 40 PVC IS ACCEPTABLE WHERE ALLOWED BY CODE. CONTRACTOR MAY USE EMT, GRS OR IMC AS ALLOWED BY CODE.
- WIRE SIZE SHALL BE MINIMUM #10 AWG, THWN SOLID COPPER UNLESS OTHERWISE NOTED. PROVIDE GROUND WIRE WHERE REQUIRED BY CODE. INCREASE WIRE SIZE TO COMPENSATE FOR VOLTAGE DROP WHERE TOTAL LENGTH OF ANY BRANCH EXCEEDS 100 FEET.
- WIRE SIZE SHALL NOT BE LESS THAN CORRESPONDING CIRCUIT BREAKER RATING AS REQUIRED BY CODE.
- MAXIMUM NUMBER OF UNGROUNDED WIRES IN ANY CONDUIT SHALL BE THREE. ADDITIONAL WIRES ARE ACCEPTABLE IF WIRE SIZE IS INCREASED TO ALLOW FOR DERATING PER CODE. PROVIDE ADDITIONAL WIRES FOR SWITCHING AS REQUIRED.
- CONDUIT SHALL BE SIZED IN ACCORDANCE WITH THE NATIONAL ELECTRIC CODE.
- RELOCATED LED FIXTURES SHALL BE CLEANED AND MADE TO AS NEW CONDITION PRIOR TO REINSTALLATION. SECURELY MOUNTED AND CHECK DRAWINGS FOR ORIENTATION.
- EACH LIGHTING CIRCUIT REQUIRES A SEPARATE NEUTRAL - NO MULTI-WIRE BRANCH CIRCUITS.
- VERIFY MOUNTING AND LOCATION OF POLE FIXTURES WITH CIVIL ENGINEER PRIOR TO INSTALLATION.
- CONTRACTOR SHALL CONNECT A RECORDING AMMETER OR POWER METER TO THE HIGHEST LOADED OF PANEL '1H1B' PHASE AND THE UPSTREAM PANELS AND SERVICE FEEDING IT TO MEASURE THE MAXIMUM DEMAND MAINTAINED FOR A 15-MINUTE INTERVAL DURING A 30-DAY PERIOD AS DESCRIBED IN NEC 220.87 TO ENSURE THAT THE NEW LOAD PLUS 125% OF THE EXISTING DEMAND LOAD DOES NOT EXCEED THE SERVICE AND FEEDER AMPACITIES.

KEY NOTES

- INSTALL NEW 13X24X1/2" AASHTO PULLBOX - QUARTZITE PG1324Z11929 OR EQUAL - SEE PULLBOX DETAIL. EXTEND AND RECONNECT CIRCUITS 1H1B-19, 21 TO LIGHT POLES AS INDICATED. CONTRACTOR SHALL VISIT SITE TO DETERMINE EXISTING WIRE AND CONDUIT SIZE PRIOR TO BID. REUSE EXISTING CONDUIT AND CONDUCTOR AS MUCH AS POSSIBLE.
- INSTALL 13X24" CONCRETE POLYMER PULLBOX - SEE PULLBOX DETAIL. EXTEND CIRCUIT 1H1B-19 TO LIGHT POLE AS INDICATED. CONTRACTOR SHALL VISIT SITE TO DETERMINE EXISTING WIRE AND CONDUIT SIZE PRIOR TO BID.
- CONNECT TO SPARE 20A/1P CIRCUIT BREAKER IN PANEL '1H1B'.
- MODIFY MULTI-WIRE BRANCH CIRCUIT FOR NEW DUAL-LEVEL DIMMABLE LUMINAIRES CONTROLLED BY AUTOMATIC OCCUPANCY SENSORS - SEE EXISTING LIGHTING CONTACTOR MODIFICATION DETAIL.
- CONTRACTOR TO FIELD TRACE EXISTING UNDERGROUND CONDUIT AND CONDUCTOR. EXTEND WITH NEW CONDUIT AND CONDUCTOR TO EXISTING LIGHT POLES OR NEW PULL BOXES SHOWN ON DRAWING.
- EXISTING LIGHT POLE FIXTURE SHALL REMAIN IN SERVICE DURING CONSTRUCTION.

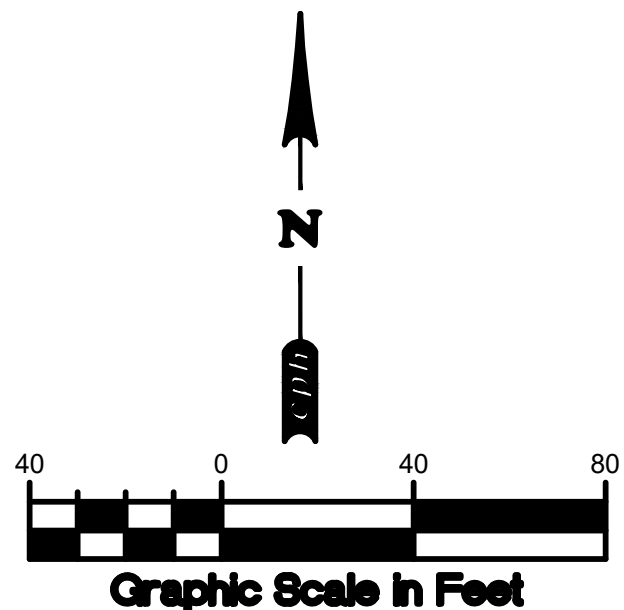


cph
www.cphcorp.com
Building Better Communities Together
1117 East Robinson Street
Orlando, FL 32801
Ph: 407.425.0452
Plans Prepared By
CPH, LLC
A Full Service A & E Firm
State of Florida License:
Engineer No. 3215
Surveyor No. LB143
Architect No. AA25000926
Landscape No. LC000298

GREGORY D. TAYLOR
No. 77811
STATE OF FLORIDA
PROFESSIONAL ENGINEER
01/09/2026
GREGORY TAYLOR, P.E.
FL REG. No. 77811

REVISIONS	
DOCUMENT HISTORY	CONFORMED SET
1/6/2026	


**UNIVERSITY HIGH SCHOOL
EXTEND PARENT LOOP**
VCS Project NO. 2548185
1000 W. RHODE ISLAND AVE., ORANGE CITY FL 32763

ARCHITECT OF RECORD Gregory D. Taylor, P.E.	
DESIGNED BY GT	DRAWN BY EP
ISSUE DATE JAN. 2025	AE PROJECT NUMBER 2400653
SHEET TITLE ELECTRICAL CONSTRUCTION PLAN	
DRAWING NO. E101	

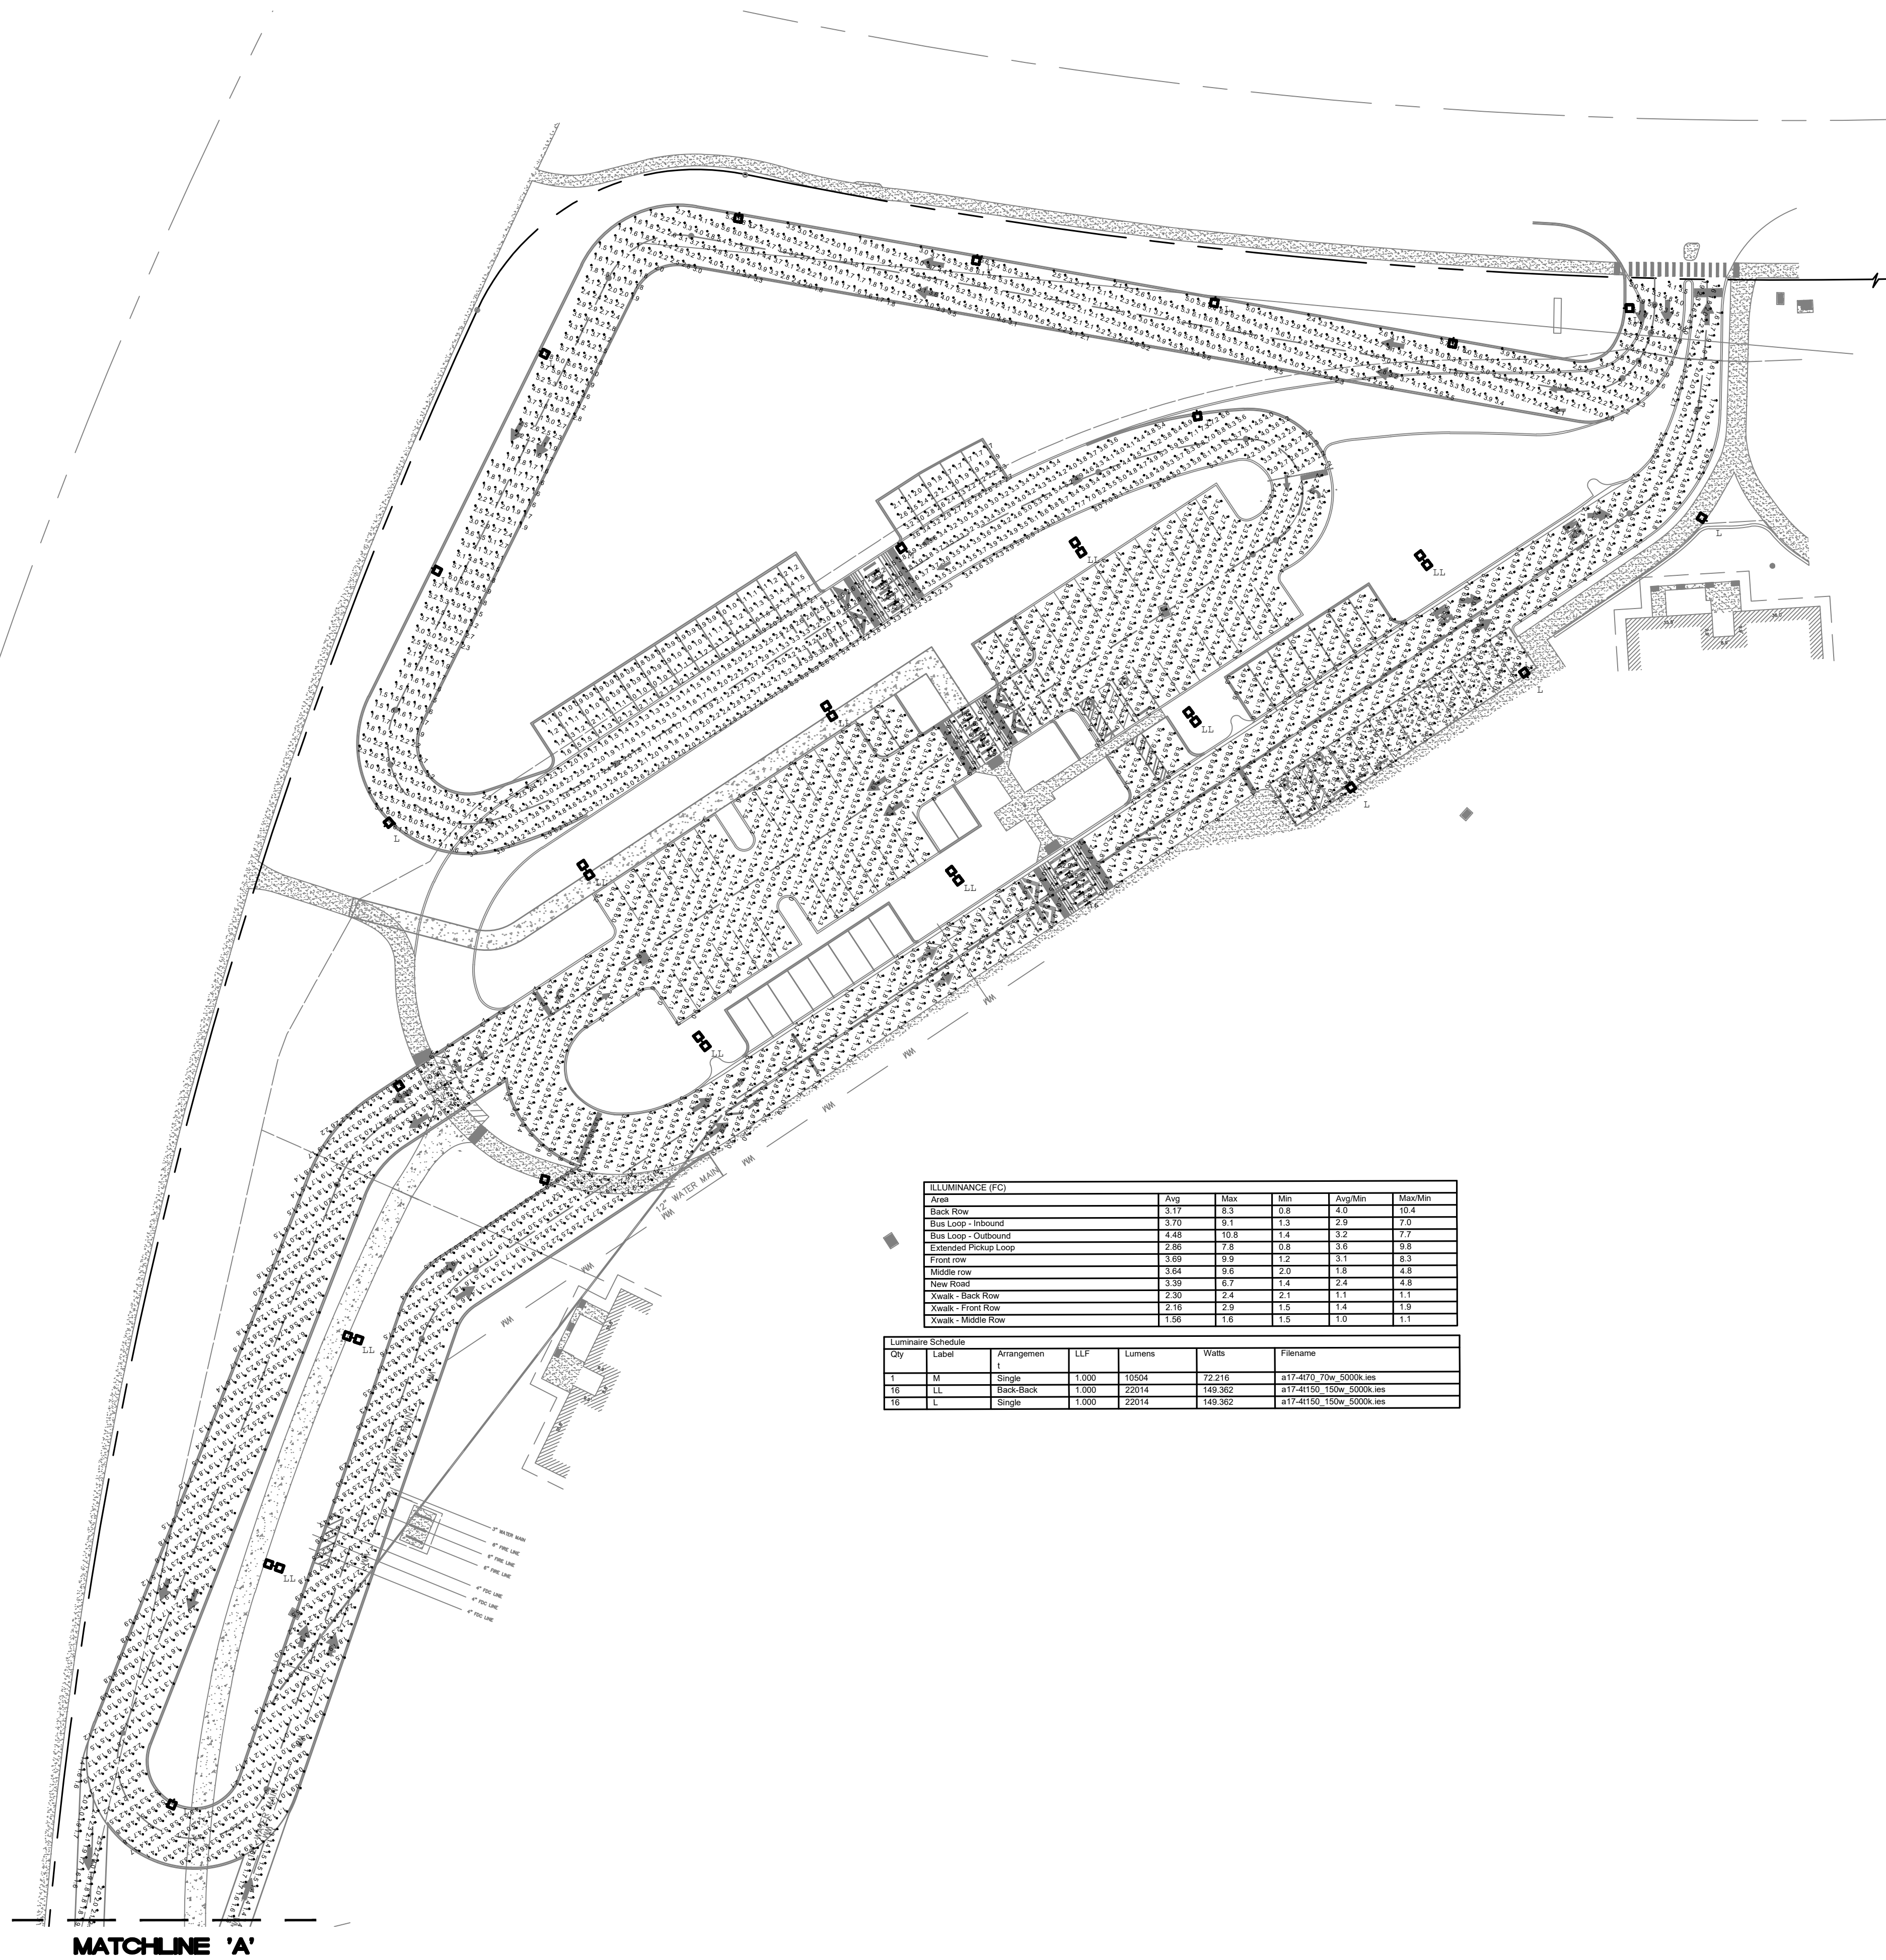

ILLUMINANCE (FC)					
Area	Avg	Max	Min	Avg/Min	Max/Min
Back Row	3.77	8.3	0.8	4.0	10.4
Bus Loop - Inbound	3.78	8.1	1.3	2.9	7.0
Bus Loop - Outbound	4.48	10.8	1.4	3.2	7.7
Extended Pickup Loop	2.88	7.8	0.8	3.6	9.8
Front row	3.68	8.9	1.2	3.1	8.3
Middle row	3.64	9.8	2.0	1.8	4.8
New Road	3.39	6.7	1.4	2.4	4.8
Xwalk - Back Row	2.30	2.4	2.1	1.1	1.1
Xwalk - Front Row	2.18	2.9	1.3	1.4	1.9
Xwalk - Middle Row	1.58	1.8	1.3	1.0	1.1

Luminaire Schedule					
Qty	Label	Arrangement	LLF	Lumens	Watts
1	M	Single	1.000	15504	72.216
18	LL	Back-Back	1.000	22014	149.362
16	L	Single	1.000	22014	149.362

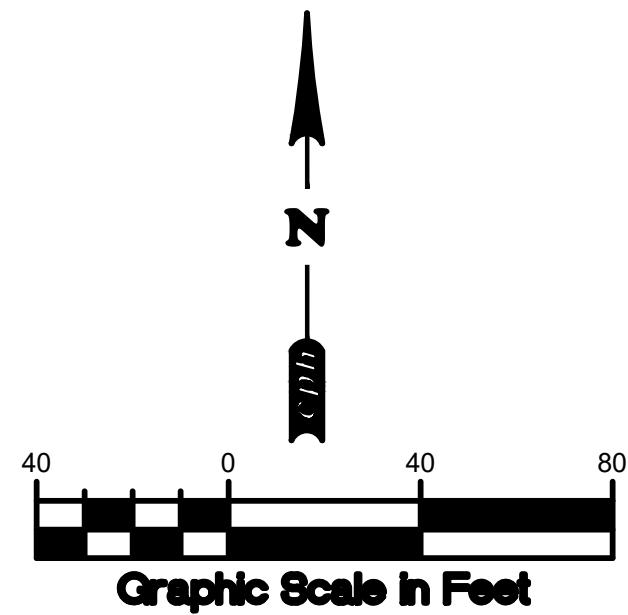

cph
www.cphcorp.com
Building Better Communities Together
1117 East Robinson Street
Orlando, FL 32801
Ph: 407.425.0452
Plans Prepared By
CPH, LLC
A Full Service A & E Firm
State of Florida Licenses:
Engineer No. 3215
Surveyor No. LB143
Architect No. AA05000926
Landscape No. LC000298


GREGORY D. TAYLOR
No. 77811
STATE OF FLORIDA
PROFESSIONAL ENGINEER
01/09/2026
GREGORY TAYLOR, P.E.
FL REG. No. 77811

REVISIONS

DOCUMENT HISTORY	CONFORMED SET
1/6/2026	

UNIVERSITY HIGH SCHOOL
EXTEND PARENT LOOP
VCS Project NO. 2548185
1000 W. RHODE ISLAND AVE., ORANGE CITY FL 32763

Gregory D. Taylor, P.E. ARCHITECT OF RECORD
DESIGNED BY: GT DRAWN BY: EP
ISSUE DATE: JAN. 2025 AE PROJECT NUMBER: 2400653
SHEET TITLE: PHOTOMETRIC SITE PLAN
DRAWING NO.: E200

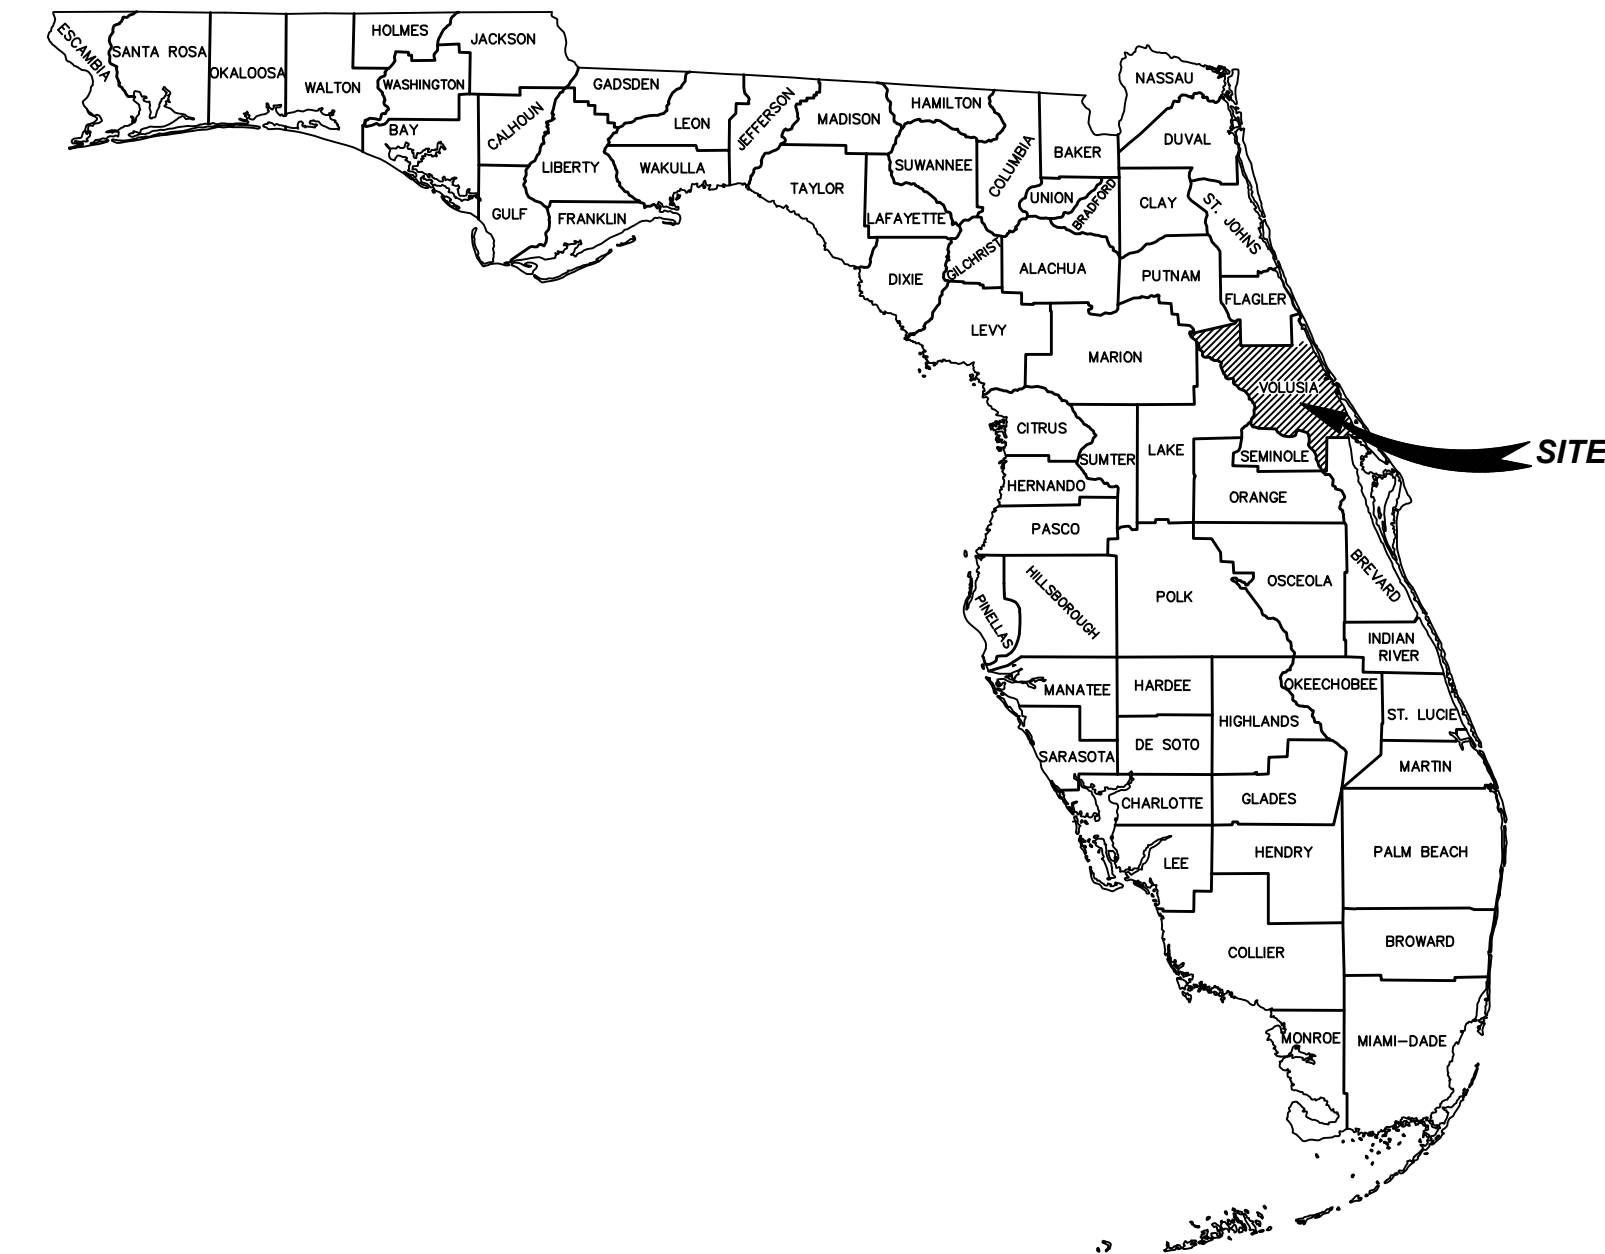

BOUNDARY & TOPOGRAPHIC SURVEY
FOR
VOLUSIA COUNTY SCHOOLS
AT
UNIVERSITY HIGH SCHOOL
1000 W RHODE ISLAND AVENUE
ORANGE CITY, FLORIDA
LYING IN
SECTION 15-TOWNSHIP 18 SOUTH-RANGE 30 EAST
VOLUSIA COUNTY, FLORIDA


Legal Description:

THE NORTH AND WEST LINES OF UNIVERSITY HIGH SCHOOL LOCATED AT 1000 W RHODE ISLAND AVENUE PER OFFICIAL RECORDS BOOK 5193, PAGE 4174 OF THE PUBLIC RECORDS OF VOLUSIA COUNTY, FLORIDA.
LESS:

RIGHT-OF-WAY REALIGNMENT OF WESTSIDE PARKWAY AND W RHODE ISLAND AVENUE PER COUNTY OF VOLUSIA PUBLIC WORKS DEPARTMENT CONSTRUCTION ENGINEERING DIVISION SPECIFIC PURPOSE SURVEY/RIGHT-OF-WAY MAP PROJECT NO. 4911.

Topographic Survey Area:

A PORTION OF UNIVERSITY HIGH SCHOOL LOCATED AT 1000 W RHODE ISLAND AVENUE AS DESIGNATED BY THE CLIENT.

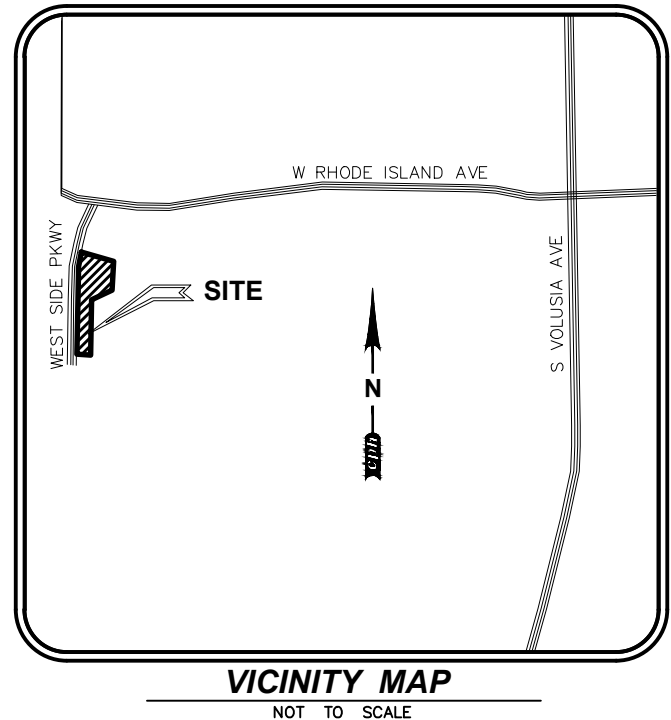

Survey Notes:

- COPIES OF THIS SURVEY ARE NOT VALID WITHOUT THE ORIGINAL SIGNATURE AND SEAL OF A FLORIDA LICENSED SURVEYOR AND MAPPER.
- ADDITIONS OR DELETIONS TO SURVEY MAPS OR REPORTS BY OTHER THAN THE SIGNING PARTY OR PARTIES IS PROHIBITED WITHOUT WRITTEN CONSENT OF THE SIGNING PARTY OR PARTIES.
- THIS SURVEY IS BASED ON THE NORTH AMERICAN VERTICAL DATUM OF 1988 (NAVD '88)

THE SITE BENCHMARKS FOR THIS TOPOGRAPHIC SURVEY ARE DISPLAYED ON THE RESPECTIVE SURVEY FILE. THESE BENCHMARKS ARE BASED ON A CLOSED VERTICAL CONTROL LOOP HAVING AN ACTUAL ERROR OF CLOSURE OF 0.010' WHICH MEETS THE ALLOWABLE CLOSURE OF 0.043'. THIS FIELDWORK WAS PERFORMED USING A TOPCON LEVEL MODEL # DL-502 AND REFERENCES THE FOLLOWING PUBLISHED BENCHMARK AS ESTABLISHED BY THE NORTH AMERICAN VERTICAL DATUM OF 1988 (NAVD '88) AND ALL VERTICAL INFORMATION INCLUDING SPOT ELEVATIONS, NOTATIONS AND THE CONTOUR LINES DERIVED THEREFROM ARE BASED ON AND MATCHED TO A VERTICAL CONTROL BENCHMARK SUPPLIED BY NGS DATA SHEETS PUBLISHED AT WWW.LABINS.ORG AS FOLLOWS:

- o) DESIGNATION #ORANGE CITY RESET, PID #AK0077
(NAVD '88) ELEVATION = 54.14

SITE BENCHMARKS ARE AS SHOWN ON SURVEY SHEET 2 AND 3 OF 3.

- THIS SURVEY IS NOT VALID WITHOUT SURVEY SHEETS 1 THROUGH 3 OF 3.

- THE LAST DAY FIELD WORK WAS PERFORMED WAS 11/26/2024.

- HAVING CONSULTED THE NATIONAL FLOOD INSURANCE PROGRAM, FLOOD INSURANCE RATE MAP (FIRM) NUMBER 12127C0615J, COMMUNITY PANEL NO. 120633-0615-J, CITY OF ORANGE CITY, REVISED DATE FEBRUARY 19, 2014, THE SUBJECT PROPERTY APPEARS TO LIE IN ZONE X, WHICH ARE AREAS DETERMINED TO BE OUTSIDE THE 0.2% ANNUAL CHANCE FLOODPLAIN (NAVD '88), THIS DETERMINATION WAS BASED ON A GRAPHIC INTERPOLATION OF SAID MAP AND NOT ON ACTUAL FIELD MEASUREMENTS.

- HORIZONTAL WELL-IDENTIFIED FEATURES IN THIS SURVEY AND MAP HAVE BEEN MEASURED TO AN ESTIMATED HORIZONTAL POSITIONAL ACCURACY OF 0.05 (FT). THE EQUIPMENT USED TO VERIFY THE HORIZONTAL CONTROL ON THE SUBJECT SURVEY WAS A TOPCON GPS HIPER V. THE EQUIPMENT USED TO LOCATE THE FEATURES WAS A LEICA SCANSTATION P40 AND A TOPCON GPS HIPER V.

- NO UNDERGROUND UTILITIES, FOUNDATIONS OR IMPROVEMENTS, IF ANY, HAVE BEEN LOCATED EXCEPT AS SHOWN.

- THIS SURVEY DOES NOT IDENTIFY THE LIMITS OR EXTENT OF POTENTIAL JURISDICTIONAL WETLAND BOUNDARIES.
- FENCES AND WALLS EXISTING ON, OVER OR ADJACENT TO SUBJECT PROPERTY, ARE DISPLAYED HEREON; OWNERSHIP WHETHER SINGULAR OR JOINT WAS NOT DETERMINED BY THIS SURVEY.

- VERTICAL FEATURE ACCURACY: "ELEVATIONS OF WELL-IDENTIFIED FEATURES CONTAINED IN THIS SURVEY AND MAP HAVE BEEN MEASURED TO AN ESTIMATED VERTICAL POSITIONAL ACCURACY OF 0.05 (FT)."
- STATE PLANE INFORMATION SHOWN HEREON IS BASED ON THE NORTH AMERICAN DATUM OF 1983 (1990) USING CONTROL POINTS FROM THE NGS DATA SHEETS PUBLISHED AT WWW.LABINS.ORG AND THE FLORIDA DEPARTMENT OF TRANSPORTATION AND ARE AS FOLLOWS:

FLORIDA EAST ZONE

- POINT NAME #91503015-1990 = N 1,664,032.489 FEET, E 567,784.365 FEET

- DESIGNATION # ORANGE CITY RESET, PID #AK0077 = N 1,675,761.24 FEET, E 558,756.72 FEET
THE EQUIPMENT USED TO TRANSFER THE STATE PLANE INFORMATION FROM THE ABOVE REFERENCED CONTROL POINTS TO THE SUBJECT SURVEY WAS A TOPCON GPS HIPER V.

- DIMENSIONS ARE SHOWN RELATIVE TO UNITED STATES STANDARD FEET AND DECIMALS THEREOF, UNLESS THE OBJECT SHOWN IS COMMONLY IDENTIFIED IN INCHES, I.E. TREE DIAMETER, PIPE DIAMETER, ETC. TREES DEPICTED ARE COMMON NAMES AND MEASURED AND LABELED AS DIAMETER AT BREAST HEIGHT IN INCHES.

- THE UNDERGROUND UTILITIES DEPICTED BY PIPE LINETYPES ARE APPROXIMATE IN NATURE BASED UPON A VISUAL INSPECTION OF THE MANHOLE, GRATE, ETC. OF EACH FACILITY. EXISTING PIPES WERE NOT LAMPED OR REMOTELY VIEWED FOR DIRECTION, OBSTRUCTIONS OR CONNECTIVITY.

- THE PURPOSE OF THIS SURVEY IS TO DEPICT COLLECTED TOPOGRAPHIC DATA ON A PORTION OF THE SITE. TOPOGRAPHIC LIMITS WERE PROVIDED BY THE CLIENT.

- BEARINGS SHOWN HEREON ARE RELATIVE TO THE WEST RIGHT-OF-WAY LINE SHOWN PER COUNTY OF VOLUSIA PUBLIC WORKS DEPARTMENT SPECIFIC PURPOSE SURVEY/RIGHT-OF-WAY MAP PROJECT NO. 4911, AS BEING S 0014°17' W.

Index of Survey Sheets

- 1 COVER SHEET
2-3 BOUNDARY & TOPOGRAPHIC SURVEY

Reference Material

1) COMPASS LANDING PHASE 2, AS RECORDED IN MAP BOOK 61, PAGES 84 THROUGH 87 OF THE PUBLIC RECORDS OF VOLUSIA COUNTY, FLORIDA.

2) COUNTY OF VOLUSIA PUBLIC WORKS DEPARTMENT CONSTRUCTION ENGINEERING DIVISION SPECIFIC PURPOSE SURVEY/RIGHT-OF-WAY MAP PROJECT NO. 4911.

Surveyor's Certification:

I hereby certify that the attached "Boundary & Topographic Survey" of the hereon-described property is true, best, to my knowledge, information and belief as surveyed in the field on November 26, 2024. I further certify that this "Boundary & Topographic Survey" meets the standards of practice set forth in Rule Chapter 5J-17 of the Florida Administrative Code, pursuant to FS 472.027.

For the Firm By: _____
Thomas J. Galloway
Professional Surveyor and Mapper
Florida Registration No. 6549

Abbreviation Legend:

(A)	- ACTUAL	MBX	- MAILBOX
A/C	- AIR CONDITIONER	MES	- MITERED END SECTION
ACSM	- AMERICANS WITH DISABILITIES ACT	MH	- MANHOLE
ADA	- AMERICANS WITH DISABILITIES ACT	MHP	- METAL LIGHT POLE
ALTA	- AMERICAN LAND TITLE ASSOCIATION	MPH	- MILES PER HOUR
APPROX	- APPROXIMATE	MPP	- METAL POWER POLE
ARV	- AIR RELEASE VALVE	N/A	- NOT APPLICABLE
AVE	- AVENUE	NAVD	- NORTH AMERICAN VERTICAL DATUM
AVG	- AVERAGE	NAD	- NORTH AMERICAN DATUM
(BB)	- BEARING BASIS	NG	- NATURAL GROUND
BFP	- BACK FLOW PREVENTER	NGS	- NATIONAL GEODETTIC SURVEY
BLK	- BLOCK	NGVD	- NATIONAL GEODETTIC VERTICAL DATUM
BLDG	- BUILDING	N & D	- NAIL AND DISK
BSL	- BACK FLOW PREVENTER	NO.	- NUMBER
BLVD	- BOULEVARD	NR	- NON-RADIAL
BM	- BENCHMARK	NSPS	- NATIONAL SOCIETY OF PROFESSIONAL SURVEYORS
BOC	- BACK OF CURB	NT	- NON-TANGENT
BOW	- BACK OF WALK	NTS	- NOT TO SCALE
BSL	- BUILDING SETBACK LINE	OD	- OUTSIDE DIAMETER
BWF	- BARBED WIRE FENCE	ORB	- OFFICIAL RECORDS BOOK
C-X	- DENOTES SHEET NUMBERING FOR ENGINEERING PLANS	OR	- OFFICIAL RECORDS
(C)	- CALCULATED	OUL	- OVERHEAD UTILITY LINES
C	- CHORD	OTL	- OVERHEAD TRAFFIC LINES
CATV	- CABLE TELEVISION RISER	PLAT	- PLAT BOOK
CB	- CHORD BEARING	PB	- PULL BOX GROUND
CBS	- CONCRETE BLOCK STRUCTURE	PB GND	- PULL BOX UNKNOWN
C.G.R.	- CERTIFIED CORNER RECORD	PC	- POINT OF CURVATURE
C&G	- CURB & GUTTER	PCC	- POINT OF COMPOUND CURVATURE
CI	- CATCH INLET	PCP	- PERMANENT CONTROL POINT
C/L	- CENTERLINE	PF	- PROPOSED FINISHED FLOOR
CLF	- CHAIN LINK FENCE	PG	- PAGE
CM	- CONCRETE MONUMENT	PGS	- PAGES
CMP	- CORRUGATED METAL PIPE	PI	- POINT OF INTERSECTION
CO	- CLEANOUT	PIV	- POST INDICATOR VALVE
CONC	- CONCRETE	PK	- PARKER KAYLON
COR	- CORNER	POB	- POINT OF BEGINNING
CRPP	- CORRUGATED PLASTIC PIPE	POC	- POINT OF COMMENCEMENT
CUE	- COUNTY UTILITY EASEMENT	POL	- POINT ON LINE
CVS	- CAN'T VERIFY SIZE	PP	- POWER POLE
CVS&T	- CAN'T VERIFY SIZE & TYPE	PPC	- POINT OF REVERSE CURVATURE
CWS	- CROSSWALK SIGNAL	PRM	- PERMANENT REFERENCE MONUMENT
(D)	- DELTA	PSM	- PROFESSIONAL SURVEYOR & MAPPER
(D)	- DESCRIPTION	PT	- POINT OF TANGENCY
DB	- DEED BOOK	PVC	- POLYVINYL CHLORIDE PIPE
DBH	- DIAMETER AT BREAST HEIGHT IN INCHES	PWMT	- PAVEMENT
DEPT	- DEPARTMENT	R	- RANGE 30 EAST
DIP	- DUCTILE IRON PIPE	RAD	- RADIUS
DR	- DRIVE	RCP	- REINFORCED CONCRETE PIPE
D/U	- DRAINAGE AND UTILITY EASEMENT	REC	- RECOVERED
(E)	- ENGINEERING PLAN	REV	- REVISION
EJB	- ELECTRIC JUNCTION BOX	R/W	- RIGHT-OF-WAY
EL	- UNDERGROUND ELECTRICAL LINES	RLS	- REGISTERED LAND SURVEYOR
ELEC	- ELECTRIC	RP	- RADIUS POINT
ELEV	- ELEVATION	RWL	- UNDERGROUND RECLAIM WATER LINE
ELLIP	- ELLIPTICAL	RWM	- RECLAIMED WATER METER
EOI	- END OF INFORMATION	SEC 15	- SPECIAL EASEMENT
EOP	- EDGE OF PAVEMENT	SMH	- SANITARY SEWER MANHOLE
FB	- FIELD BOOK	(SP)	- STATE PLANE
FDC	- FIRE DEPARTMENT CONNECTION	SQ	- SQUARE
FDOT	- FLORIDA DEPARTMENT OF TRANSPORTATION	SQ FT	- SQUARE FEET
FF	- FINISH FLOOR	SRP	- SPIRAL RIB PIPE
FOI	- FLAT GRATE INLET	ST	- STREET
FGLP	- FIBERGLASS LIGHT POLE	STMH	- STORM DRAINAGE MANHOLE
FHYD	- FIRE HYDRANT	S/W	- SIDEWALK
FM	- FORCE MAIN	TB	- TANGENT BEARING
FND	- FOUND	T18S	- TOWNSHIP 18 SOUTH
FP&L	- FLORIDA POWER AND LIGHT	TELE	- TELEPHONE
(G)	- GRID (STATE PLANE)	TL	- OVERHEAD TRAFFIC SIGNAL LINES
GL	- UNDERGROUND GAS LINES	TOB	- TOP OF BANK
GOVT	- GOVERNMENT	TOE	- TOE OF SLOPE
GPR	- GROUND PENETRATING RADAR	TR	- TELEPHONE RISER
GTH	- GREASE TRAP MANHOLE	TRANS	- TRANSFORMER
HDPE	- HIGH DENSITY POLYETHYLENE PIPE	TSB	- TRAFFIC SIGNAL BOX
HWF	- HOG WIRE FENCE	TSSP	- TRAFFIC SIGNAL SUPPORT POLE
ID	- IDENTIFICATION	TVL	- UNDERGROUND CABLE TV LINES
ICV	- IRRIGATION CONTROL VALVE	(TYP)	- TYPICAL
INV	- INVERT	UE	- UTILITY EASEMENT
IP	- IRON PIPE	UNK	- UNKNOWN
IP&C	- IRON PIPE & CAP	UTL	- UNDERGROUND TELEPHONE LINES
IR&C	- IRON ROD	W/	- WITH
IRR	- IRRIGATION	WF	- WROUGHT IRON FENCE
LB	- ARC LENGTH	WL	- UNDERGROUND WATER LINE
LB#	- LICENSED BUSINESS NUMBER	WLP	- WOOD LIGHT POLE
LG	- LIGHT POLE	WM	- WATER METER
(M)	- MEASURED	WP	- WORK PROGRAM
MAG	- MAGNETIC	WPF	- WOOD POST FENCE
MB	- MAP BOOK	WPP	- WOOD POWER POLE
		WV	- WATER VALVE

Line Legend:

NOT TO SCALE

---	1	---	= 1 FOOT CONTOURS
---	5	---	= 5 FOOT CONTOURS
---	---	---	= ADJOINER PROPERTY LINES
---	X	---	= BARBED WIRE FENCE
---	---	---	= BROKEN LINE
---	UC	---	= BURIED CABLE
---	UCTV	---	= BURIED CABLE TELEVISION
---	UE	---	= BURIED ELECTRIC
---	UFO	---	= BURIED FIBER OPTICS
---	UG	---	= BURIED GAS
---	URW	---	= BURIED RECLAIMED WATER LINE
---	SAN	---	= BURIED SANITARY LINES
---	FM	---	= BURIED SANITARY SEWER FORCE MAIN LINE
---	TC	---	= BURIED TRAFFIC CONTROL
---	UT	---	= BURIED TELEPHONE LINE
---	UW	---	= BURIED WATER LINES
---	---	---	= CENTER LINE R/W
---	---	---	= CHAIN LINK FENCE
---	---	---	= EASEMENT LINES (EXISTING)
---	---	---	= EASEMENT LINES (PROPOSED)
---	EDW	---	= EDGE OF WATER LINES
---	---	---	= EXISTING DRAINAGE PIPES
---	---	---	= EXISTING DRAINAGE PIPES (TERMINUS & ANGLE UNKNOWN)
---	FW	---	= FIRE WATER MAIN LINES
---	HW	---	= HOT WATER SUPPLY LINES
---	RR	---	= IRRIGATION LINES
---	OTL	---	= OVERHEAD TRAFFIC LINES
---	OUU	---	= OVERHEAD UTILITY LINES
---	---	---	= RAILROAD TRACKS
---	---	---	= RIGHT-OF-WAY LINES
---	---	---	= SECTION LINES
---	---	---	= STONE WALL LINES
---	TOB	---	= TOP OF BANK LINES
---	TOE	---	= TOE OF SLOPE LINES
---	---	---	= TREE LINES
---	TRAV	---	= TRAVERSE LINES
---	UNK	---	= UNKNOWN BURIED LINES
---	---	---	= VINYL FENCE
---	---	---	= WOOD FENCE
---	---	---	= WROUGHT IRON FENCE
---	---	---	= WOOD POST FENCE
---	---	---	= WOOD POWER POLE
---	---	---	= WATER VALVE

Symbol Legend:

NOT TO SCALE

ARV	- AIR RELEASE VALVE	MAILBOX	- MAILBOX
BH	- BORING HOLE LOCATION	MONITOR WELLS	- MONITOR WELLS
BP	- BRICK PAVERS	NAIL & DISC (AS NOTED)	- NAIL & DISC (AS NOTED)
CTV	- CABLE TV RISER	PARKING SPACES (2)	- PARKING SPACES (2)
CA	- CENTRAL ANGLE	POST INDICATOR VALVE	- POST INDICATOR VALVE
CO	- CLEAN OUT	PULL BOX (AS NOTED)	- PULL BOX (AS NOTED)
CMH	- COMMUNICATION MANHOLE	REVISION NUMBER (3)	- REVISION NUMBER (3)
CONC	- CONCRETE	RECLAIMED WATER MARKER	- RECLAIMED WATER MARKER
CLP	- CONCRETE LIGHT POLE	RECLAIMED WATER METER	- RECLAIMED WATER METER
CLPD	- CONCRETE LIGHT POLE (DUAL)	RECLAIMED WATER RISER	- RECLAIMED WATER RISER
CLPT	- CONCRETE LIGHT POLE (TRIPLE)	RECLAIMED WATER VALVE	- RECLAIMED WATER VALVE
CMED	- CONCRETE MITERED END SECTION	ROOF DRAIN	- ROOF DRAIN
CP	- CONCRETE PAVERS	SANITARY SEWER MANHOLE	- SANITARY SEWER MANHOLE
CRP	- CONCRETE RIP RAP	SANITARY SEWER MARKER	- SANITARY SEWER MARKER
CU	- CONCRETE UTILITY POLE	SANITARY SEWER VALVE	- SANITARY SEWER VALVE
CUS	- COUNTY ROAD SYMBOL	TITLE OR REPORT ITEM NUMBER	- TITLE OR REPORT ITEM NUMBER
CWS	- CROSSWALK SIGNAL POLE	SECTION CORNER	- SECTION CORNER
DA	- DETECTABLE WARNING AREA	4" X 4" CM LB #7143	- 4" X 4" CM LB #7143
DS	- DUAL SUPPORT SIGN	5/8" IR&C LB #7143	- 5/8" IR&C LB #7143
EM	- ELECTRICAL MANHOLE	SIGN	- SIGN
ELM	- ELECTRIC METER	SITE BENCH MARK	- SITE BENCH MARK
EJB	- ELECTRICAL JUNCTION BOX	STORM SEWER MANHOLE	- STORM SEWER MANHOLE
EO	- ELECTRIC OUTLET	STRIPING (DIRECTIONAL)	- STRIPING (DIRECTIONAL)
ER	- ELECTRIC RISER	TELEPHONE CABLE RISER	- TELEPHONE CABLE RISER
FOM	- FIBER OPTIC MARKER	TELEPHONE MANHOLE	- TELEPHONE MANHOLE
FDC	- FIRE DEPARTMENT CONNECTION	TELEPHONE LINE MARKER	- TELEPHONE LINE MARKER
FD	- FIRE HYDRANT	TELEPHONE JUNCTION BOX	- TELEPHONE JUNCTION BOX
FL	- FLOOD LIGHT	TELEPHONE REPEATER	- TELEPHONE REPEATER
FCM	- FOUND CONCRETE MONUMENT (AS NOTED)	TEST HOLE	- TEST HOLE
FR	- FOUND IRON PIPE (AS NOTED)	TRAFFIC SIGNAL BOX	- TRAFFIC SIGNAL BOX
FRB	- FOUND IRON REBAR (AS NOTED)	TRAFFIC SIGNAL SUPPORT POLE	- TRAFFIC SIGNAL SUPPORT POLE
FS	- FOUND/SET NAIL (AS NOTED)	UNKNOWN MANHOLE	- UNKNOWN MANHOLE
G	- GARBAGE CAN	UNKNOWN UTILITY MARKER	- UNKNOWN UTILITY MARKER
GM	- GAS MARKER	UNKNOWN RISER	- UNKNOWN RISER
GV	- GAS VALVE	UNKNOWN VALVE	- UNKNOWN VALVE
GTH	- GOPHER TORTOISE HOLE	UTILITY FLAG (AS NOTED)	- UTILITY FLAG (AS NOTED)
GI	- GRATE INLET	VENT (AS NOTED)	- VENT (AS NOTED)
GRL	- GRAVEL/DIRT	WATER METER	- WATER METER
GPM	- GREASE TRAP MANHOLE	WATER RISER	- WATER RISER
GL	- GROUND LIGHT	WATER SERVICE	- WATER SERVICE
GA	- GUY ANCHOR	WATER SPIGOT	- WATER SPIGOT
H	- HANDICAP PARKING SPACE	WATER SPRINKLER	- WATER SPRINKLER
IS	- INTERSTATE SYMBOL	WATER VALVE	- WATER VALVE
IRV	- IRRIGATION CONTROL VALVE	WELL	- WELL
LP	- LIGHT POLE	WETLAND FLAG	- WETLAND FLAG
LD	- LIGHT POLE (DUAL)	WOOD UTILITY POLE	- WOOD UTILITY POLE
LDL	- LIGHT POLE (TRIPLE)	WOOD LINE MARKER	- WOOD LINE MARKER
LDL	- LIGHT POLE (QUAD)	WIRE HEIGHTS (SEE CHART)	- WIRE HEIGHTS (SEE CHART)

cph
www.cphcorp.com
Building Better Communities Together
500 West Fulton Street
Sanford, FL 32771
Ph: 407.322.6841
Plans Prepared By:
CPH, LLC
A Full Service A & E Firm
State of Florida License:
Survey No. LB7143

REVISIONS

DOCUMENT HISTORY	CONFORMED SET
1/6/2026	

UNIVERSITY HIGH SCHOOL
EXTEND PARENT LOOP

VCS Project NO. 2548185

1000 W. RHODE ISLAND AVE., ORANGE CITY FL 32763

SURVEYOR OF RECORD

Thomas J. Galloway, PSM

APPROVED BY TJG	DRAWN BY RDB
---------------------------	------------------------


ISSUE DATE 02.07.25	AE PROJECT NUMBER 2400653
-------------------------------	-------------------------------------

SHEET TITLE

COVER SHEET

DRAWING NO.

V0.1

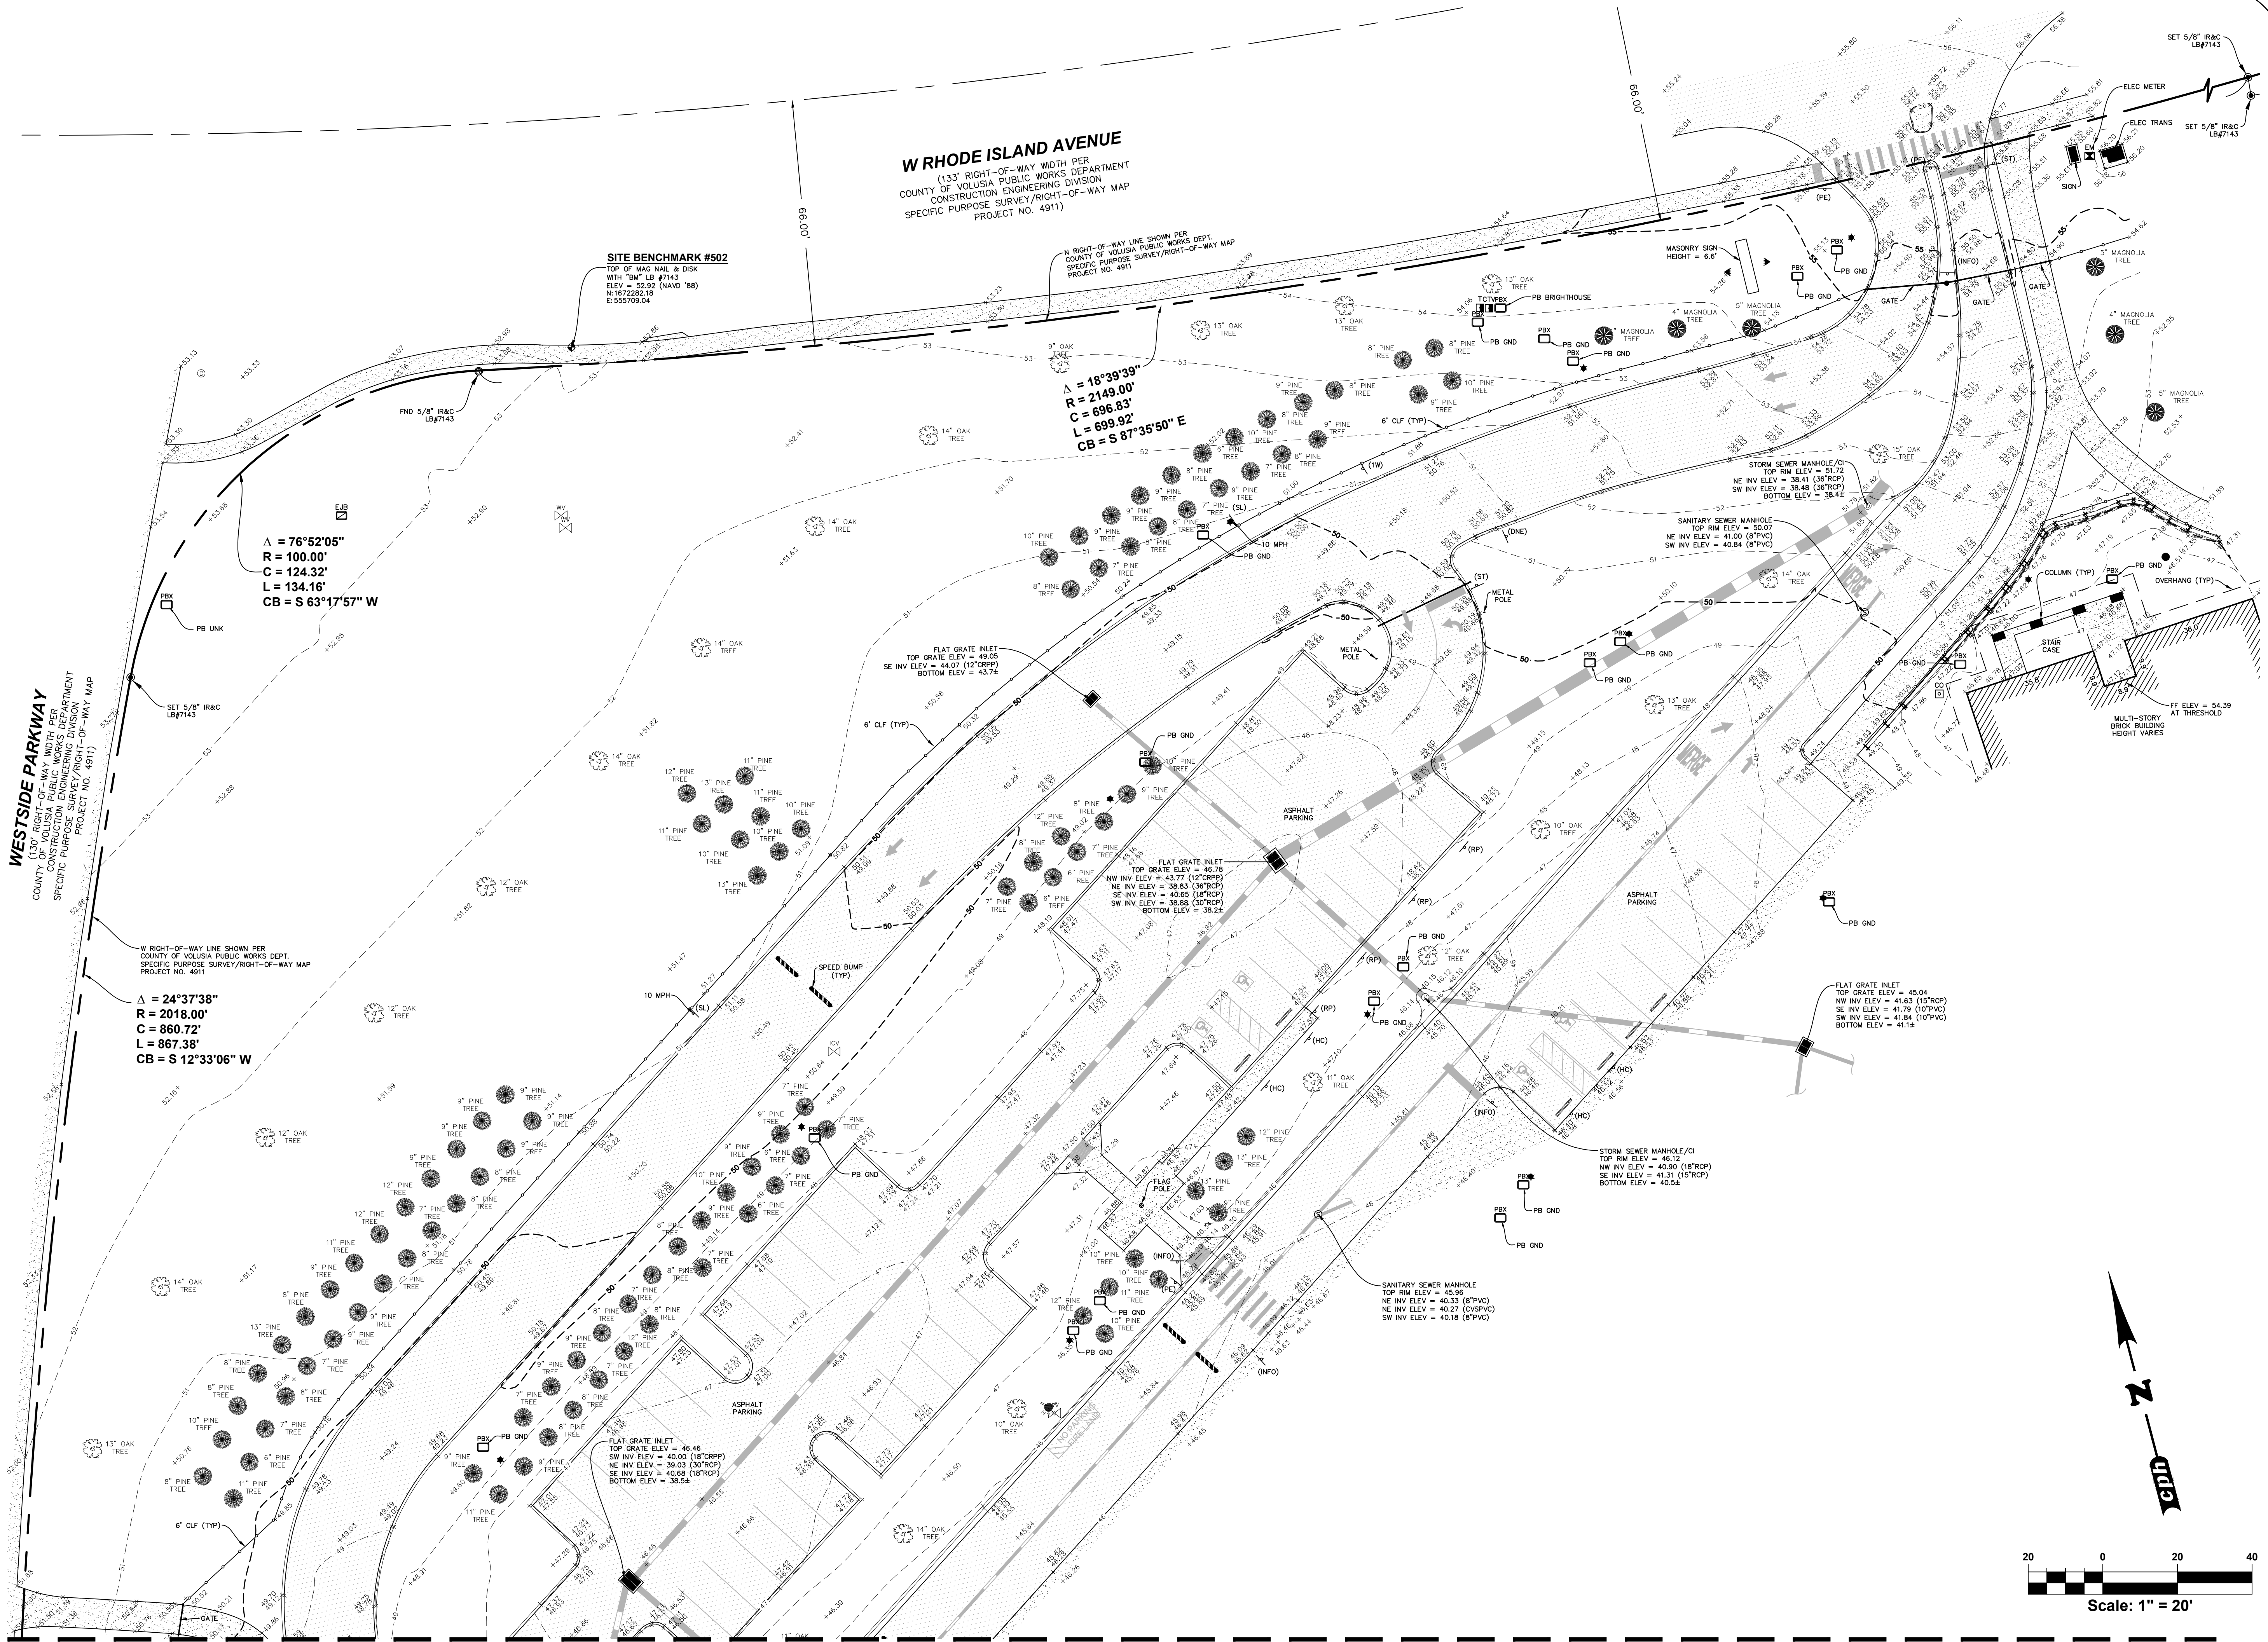

MATCHLINE "A" - SEE SURVEY SHEET 3 OF 3

cph
www.cphcorp.com
**Building Better
Communities Together**
500 West Fulton Street
Sanford, FL 32771
Ph: 407.322.6841
Plans Prepared By:
CPH, LLC
A Full Service A & E Firm
State of Florida License:
Survey No. LB7143

REVISIONS	
DOCUMENT HISTORY	CONFORMED SET
JUN/2026	

UNIVERSITY HIGH SCHOOL
EXTEND PARENT LOOP
VCS Project NO. 2548185
1000 W. RHODE ISLAND AVE., ORANGE CITY FL 32763

SURVEYOR OF RECORD	
Thomas J. Galloway, PSM	
APPROVED BY TJG	DRAWN BY RDB
ISSUE DATE 02.07.25	AE PROJECT NUMBER 2400653
SHEET TITLE TOPOGRAPHIC SURVEY	
DRAWING NO. V1.1	

