


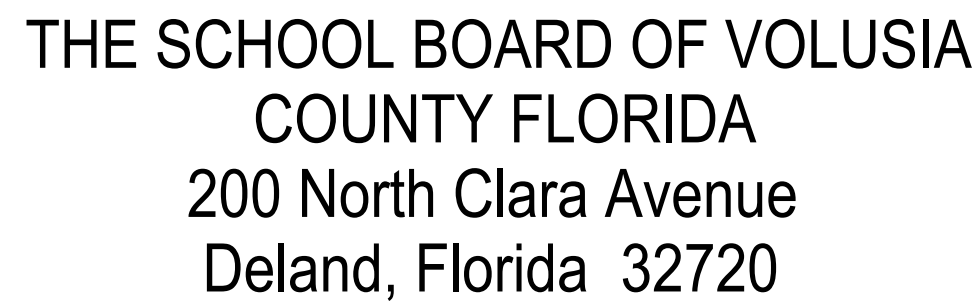

1001 PARNELL COURT  
DELTONA, FLORIDA 32738

|                  |                  |
|------------------|------------------|
| RUBEN COLÓN      | BOARD CHAIR      |
| KRISTA GOODRICH  | BOARD VICE CHAIR |
| DONNA BROSEMER   | MEMBER           |
| JAMIE HAYNES     | MEMBER           |
| JESSICA THOMPSON | MEMBER           |

DR. CARMEN J. BALGOBIN SUPERINTENDENT



**HALL & OGLE**  
**ARCHITECTS, INC.**

208 MAGNOLIA AVENUE  
 DAYTONA BEACH, FLORIDA 32114  
 PH (386) 255-6163  
 FAX (386) 257-6650  
 AA-C000925  
[www.hoarchitects.com](http://www.hoarchitects.com)


CONSTRUCT NEW DIGITAL MARQUEE AND PROVIDE ELECTRICAL/DATA, LANDSCAPING, AND FENCING.

To the best of my knowledge, these drawings and the project manual are complete and comply with the Florida Building Code.

|    |                     |     |
|----|---------------------|-----|
| A. | SURVEY PARCEL ID    | N/A |
| B. | LEGAL DESCRIPTION   | N/A |
| C. | OCCUPANCY TYPE      | N/A |
| D. | CONSTRUCTION TYPE   | N/A |
| E. | RISK CATEGORY       | N/A |
| F. | AUTOMATIC SPRINKLER | N/A |
| G. | BUILDING AREA       | N/A |
| H. | BUILDING HEIGHT     | N/A |
| I. | OCCUPANT LOAD       | N/A |

NOT TO SCALE

MECHANICAL / PLUMBING / ELECTRICAL  
MATERN PROFESSIONAL ENGINEERING  
130 CANDACE DRIVE  
MAITLAND, FLORIDA 32751  
407-740-5020  
PROJECT MANAGER - ADRIAN BAUS  
abaus@matern.net  
WWW.MATERN.NET

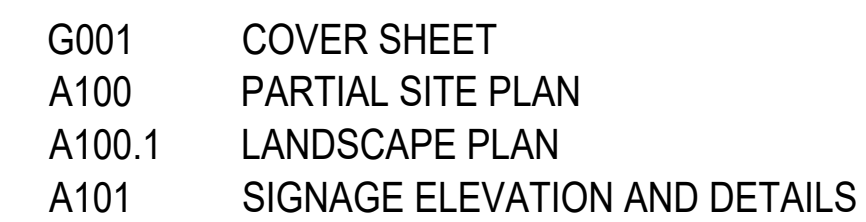

|      |                                           |
|------|-------------------------------------------|
| E001 | GENERAL NOTES AND LEGENDS - ELECTRICAL    |
| E100 | PARTIAL SITE PLAN - ELECTRICAL            |
| E101 | SIGNAGE PLANS AND ELEVATIONS - ELECTRICAL |
| E501 | DETAILS - ELECTRICAL                      |

28 JANUARY 2026


[illegible]

HERITAGE MIDDLE  
DIGITAL MARQUEE  
VCS Project NO. 2648217  
1001 PARNELL CT. DELTONA, FLORIDA

|                                |  |                           |  |
|--------------------------------|--|---------------------------|--|
| DESIGNED BY<br>DO              |  | DRAWN BY<br>DO/ JB        |  |
| ISSUE DATE<br>01/28/2026       |  | AE PROJECT NUMBER<br>2517 |  |
| SHEET TITLE<br><br>COVER SHEET |  |                           |  |
| DRAWING NO.<br><br>G001        |  |                           |  |





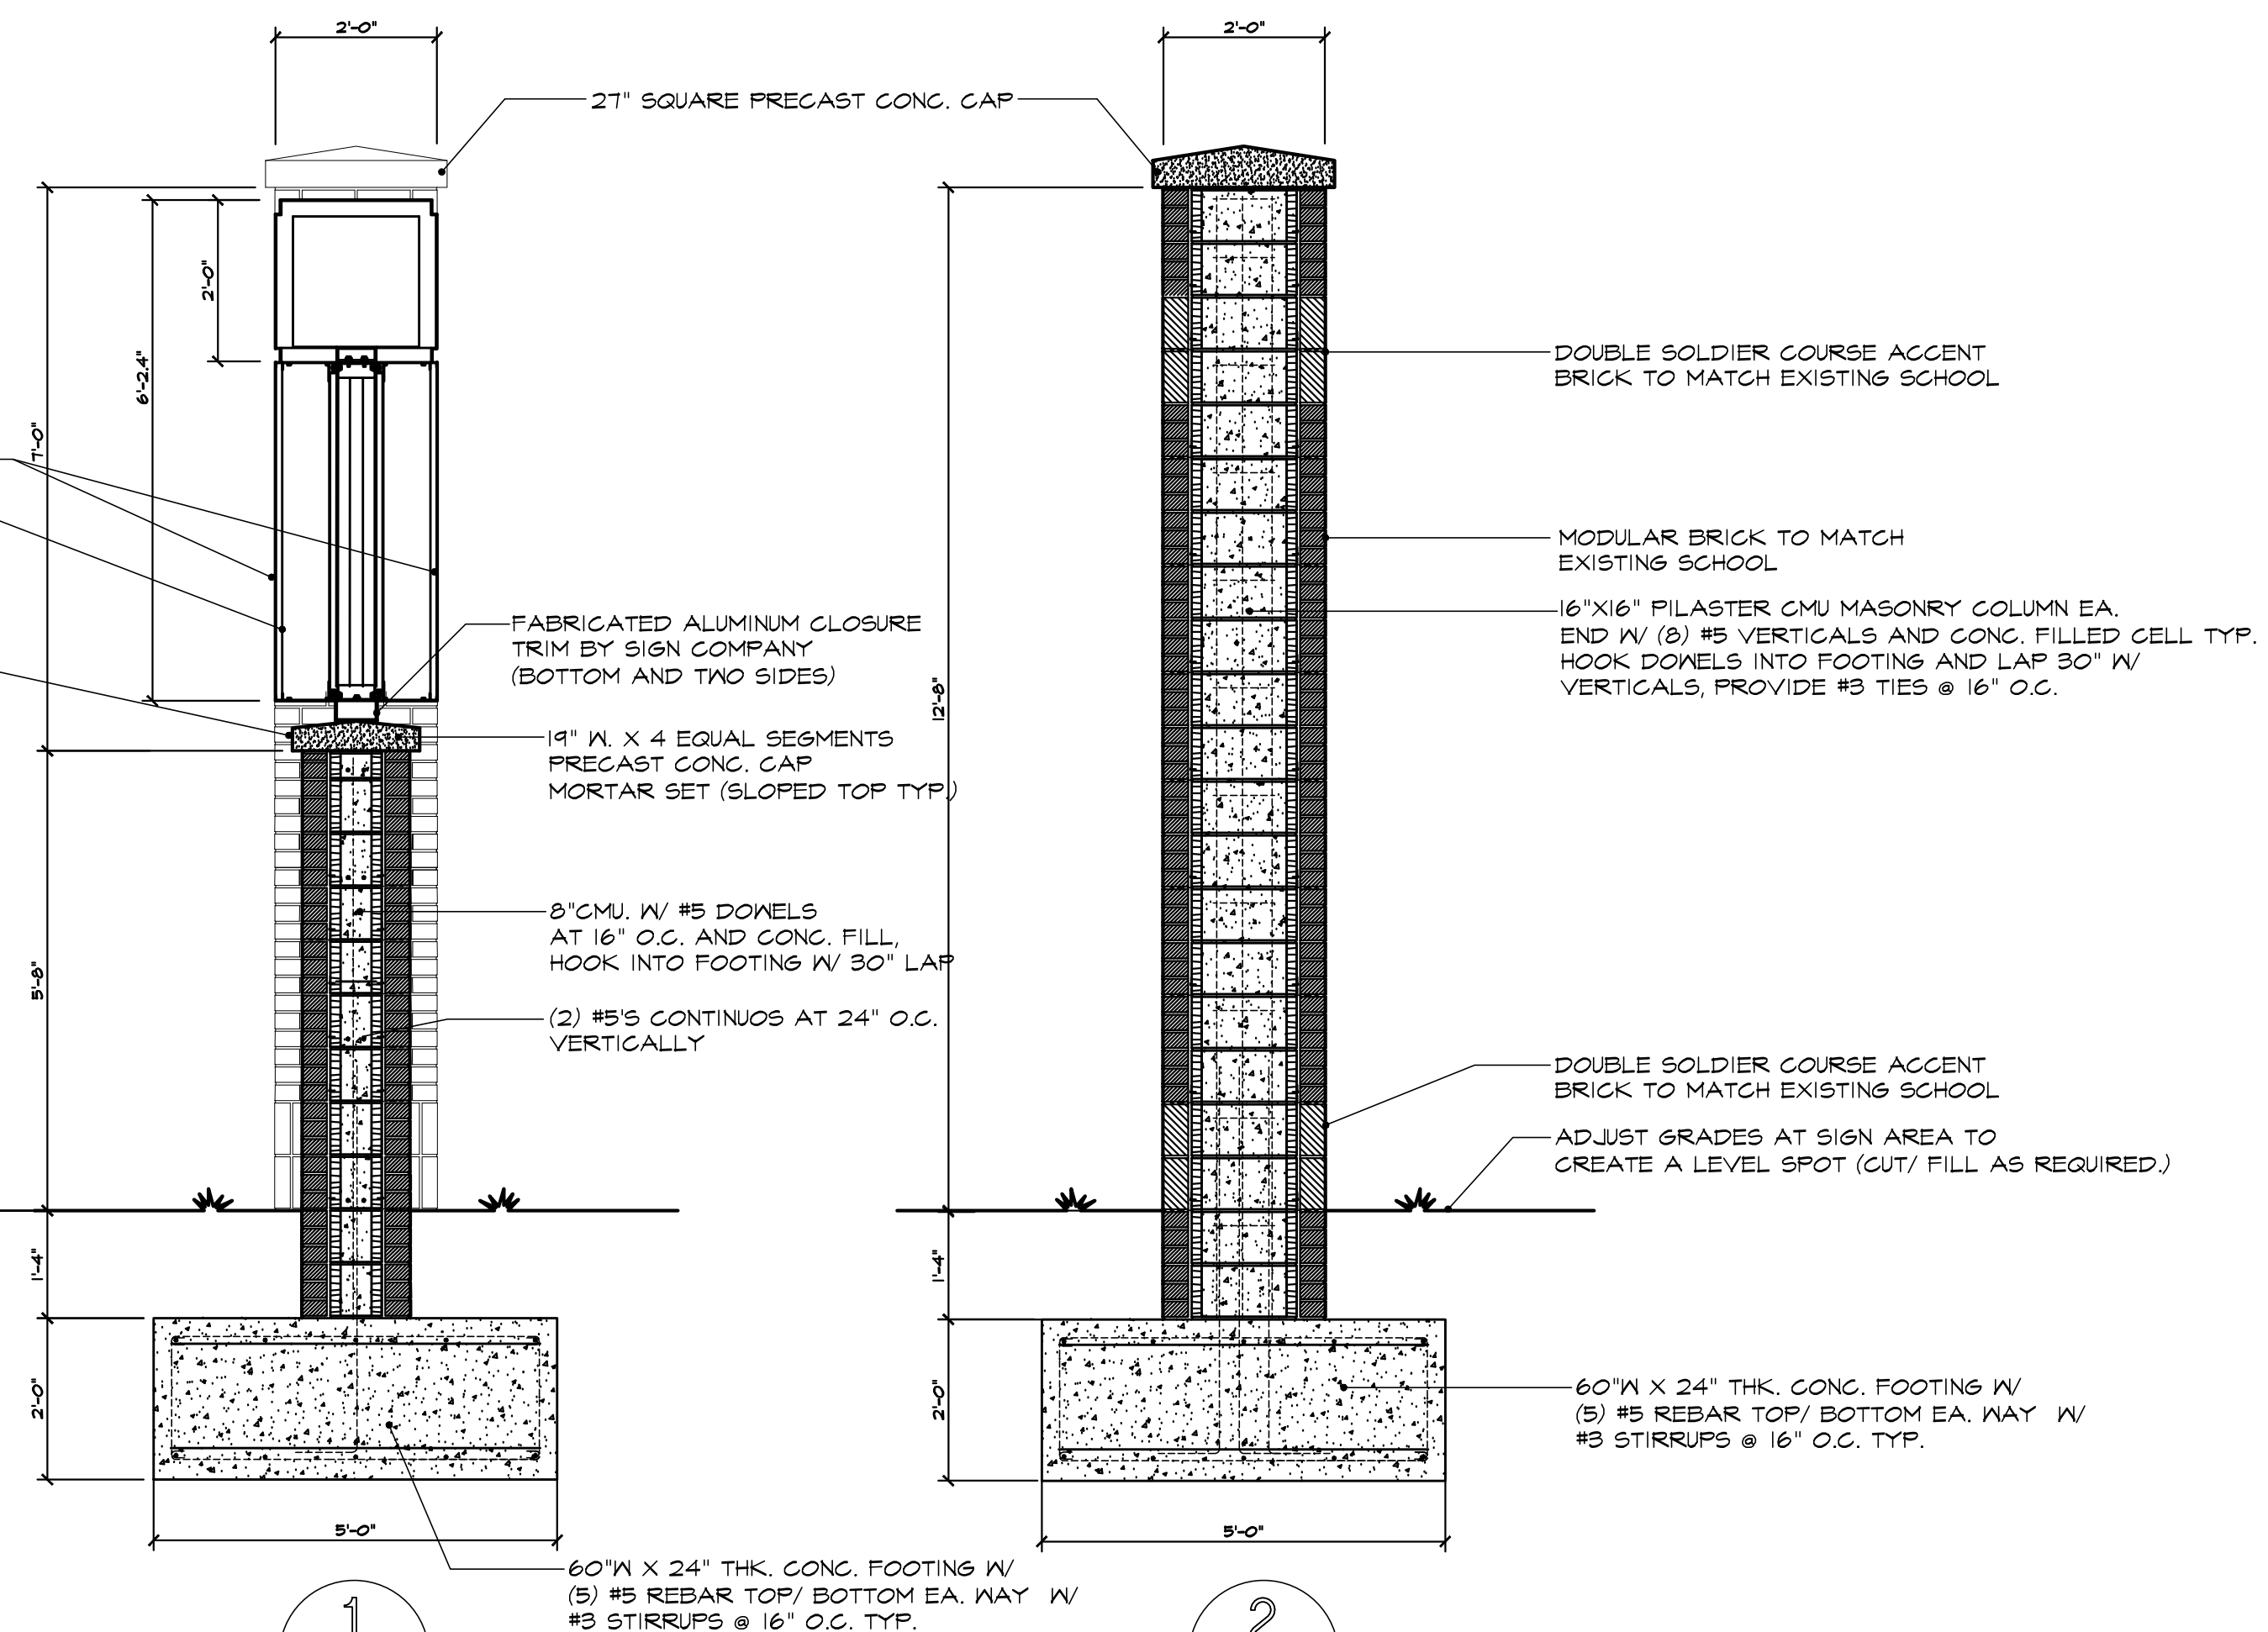

SCALE:  $\frac{1}{2}" = 1'-0"$

 


DESIGN CODE: FLORIDA BUILDING CODE EIGHTH EDITION (2023)  
OCCUPANCY GROUP: U UTILITY/ MISC.  
RISK CATEGORY: II  
EXPOSURE CATEGORY: B  
TYPE OF CONSTRUCTION: SIGN BASE MASONRY CONST.  
SIGN CABINET/ FACE/ STRUCT. BY SIGN CO.  
WIND LOADS: ASCET-10  
WIND SPEED: 155 MPH BASIC WIND SPEED (ULT.)  
NORMAL WIND SPEED: 120 MPH (ASD)  
NOTE: SIGN CO. TO PROVIDE STRUCTURAL  
ENGINEERING (FLA. REG. ENG.) FOR  
ALL SIGNAGE AND REQUIRED ATTACHMENT  
TO MASONRY AREAS PER LOCATIONS  
SHOWN. REF. STRUCTURAL DATA ABOVE

FOUNDATION SHOWN BELOW (DASHED LINES)

FOUNDATION SHOWN BELOW (DASHED LINES)

SCALE:  $\frac{1}{2}" = 1'-0"$



SIDE CONNECTION

SCALE: 1 1/2" = 1'-0"

| DOCUMENT HISTORY |      |             |
|------------------|------|-------------|
| NO               | DATE | DESCRIPTION |

HERITAGE MIDDLE  
DIGITAL MARQUEE  
VCS Project NO. 2648217  
1001 PARNELL CT. DELTONA, FLORIDA

ARCH/ENGR OF RECORD  
JOHN E. HALL AR0010727  
DAVID D. OGLE AR93986

|                   |                    |
|-------------------|--------------------|
| DESIGNED BY<br>DO | DRAWN BY<br>DO/ JB |
|-------------------|--------------------|

|            |                   |
|------------|-------------------|
| ISSUE DATE | AE PROJECT NUMBER |
| 01/28/2026 | 2517              |

## SIGNAGE ELEVATION AND DETAILS

DRAWING NO.

A101

GENERAL NOTES

- NO MULTI-WIRE BRANCH CIRCUITS ARE TO BE USED. EACH CIRCUIT IS TO HAVE SEPARATE INDIVIDUAL NEUTRAL.
2. 120 VOLT BRANCH CIRCUITS, WHERE THE LENGTH OF CIRCUIT CONDUCTORS COMPLETE FROM CIRCUIT BREAKER IN SOURCE PANEL TO ANY DEVICE ON THE CIRCUIT IS 0-100 FEET, ARE TO HAVE #12 MINIMUM BRANCH CIRCUIT WIRING THROUGHOUT CIRCUIT. (CONDUIT SIZE PER SPECIFICATION AND NEC).
3. 120 VOLT BRANCH CIRCUITS, WHERE THE LENGTH OF CIRCUIT CONDUCTORS COMPLETE FROM CIRCUIT BREAKER IN SOURCE PANEL TO ANY DEVICE ON THE CIRCUIT IS 101-125 FEET, ARE TO HAVE #10 MINIMUM BRANCH CIRCUIT WIRING THROUGHOUT CIRCUIT (3/4"). FROM PANEL CIRCUIT BREAKER TO FIRST DEVICE AND #12 BRANCH CIRCUIT WIRING THROUGHOUT THE REMAINDER OF THE CIRCUIT. (CONDUIT SIZE PER SPECIFICATION AND NEC). NOT LESS THAN THE FIRST 75 FEET OF COMBINED HOMERUN AND BRANCH CIRCUIT TO BE MINIMUM #10 WIRE (3/4").
4. 120 VOLT BRANCH CIRCUITS, WHERE THE LENGTH OF CIRCUIT CONDUCTORS COMPLETE FROM CIRCUIT BREAKER IN SOURCE PANEL TO ANY DEVICE ON THE CIRCUIT IS 126-160 FEET, ARE TO HAVE #10 MINIMUM BRANCH CIRCUIT WIRING THROUGHOUT CIRCUIT (3/4").
5. 120 VOLT BRANCH CIRCUITS, WHERE THE LENGTH OF CIRCUIT CONDUCTORS COMPLETE FROM CIRCUIT BREAKER IN SOURCE PANEL TO ANY DEVICE ON THE CIRCUIT IS 161-205 FEET, ARE TO HAVE #8 MINIMUM BRANCH CIRCUIT WIRING THROUGHOUT THE REMAINDER OF THE CIRCUIT (3/4"). NOT LESS THAN THE FIRST 125 FEET OF COMBINED HOMERUN AND BRANCH CIRCUIT TO BE MINIMUM #8 WIRE (1").
6. 120 VOLT BRANCH CIRCUITS, WHERE THE LENGTH OF CIRCUIT CONDUCTORS COMPLETE FROM CIRCUIT BREAKER IN SOURCE PANEL TO ANY DEVICE ON THE CIRCUIT IS 206-230 FEET, ARE TO HAVE #8 MINIMUM BRANCH CIRCUIT WIRING THROUGHOUT CIRCUIT (1").
7. 120 VOLT BRANCH CIRCUITS, WHERE THE LENGTH OF CIRCUIT CONDUCTORS COMPLETE FROM CIRCUIT BREAKER IN SOURCE PANEL TO ANY DEVICE ON THE CIRCUIT IS 231-250 FEET, ARE TO HAVE #6 MINIMUM BRANCH CIRCUIT WIRING THROUGHOUT THE REMAINDER OF THE CIRCUIT (1"). NOT LESS THAN THE FIRST 175 FEET OF COMBINED HOMERUN AND BRANCH CIRCUIT TO BE MINIMUM #6 WIRE (1-1/4").
8. 120 VOLT BRANCH CIRCUITS, WHERE THE LENGTH OF CIRCUIT CONDUCTORS COMPLETE FROM CIRCUIT BREAKER IN SOURCE PANEL TO ANY DEVICE ON THE CIRCUIT IS 251-325 FEET, ARE TO HAVE #6 MINIMUM BRANCH CIRCUIT WIRING THROUGHOUT THE REMAINDER OF THE CIRCUIT (1"). NOT LESS THAN THE FIRST 250 FEET OF COMBINED HOMERUN AND BRANCH CIRCUIT TO BE MINIMUM #6 WIRE (1-1/4").
9. 120 VOLT BRANCH CIRCUITS, WHERE THE LENGTH OF CIRCUIT CONDUCTORS COMPLETE FROM CIRCUIT BREAKER IN SOURCE PANEL TO ANY DEVICE ON THE CIRCUIT IS 326-370 FEET FROM THE PANEL, ARE TO HAVE #6 MINIMUM BRANCH CIRCUIT WIRING THROUGHOUT CIRCUIT (1-1/4").
10. ALL 277V, 20A CIRCUITS WITH HOMERUNS LESS THAN 70 FEET SHALL BE #12 CU. MINIMUM THROUGHOUT CIRCUIT UNLESS OTHERWISE NOTED (CONDUIT SIZE PER SPECIFICATION AND NEC). THE HOMERUN LENGTH IS THE LENGTH OF THE CIRCUIT CONDUCTORS FROM THE FIRST LIGHT FIXTURE/LOAD TO THE BREAKER IN THE SOURCE PANEL.
11. ALL 277V, 20A CIRCUITS WITH HOMERUNS 71-100 FEET SHALL BE #10 CU. MINIMUM FOR HOMERUN (3/4"), WITH #12 FOR REMAINDER OF CIRCUIT UNLESS OTHERWISE NOTED (CONDUIT SIZE PER SPECIFICATION AND NEC). THE HOMERUN LENGTH IS THE LENGTH OF THE CIRCUIT CONDUCTORS FROM THE FIRST LIGHT FIXTURE/LOAD TO THE BREAKER IN THE SOURCE PANEL.
12. ALL 277V, 20A CIRCUITS WITH HOMERUNS 101-150 FEET SHALL BE #10 CU. MINIMUM FOR HOMERUN (3/4"), WITH #10 FOR REMAINDER OF CIRCUIT UNLESS OTHERWISE NOTED (CONDUIT SIZE PER SPECIFICATION AND NEC). THE HOMERUN LENGTH IS THE LENGTH OF THE CIRCUIT CONDUCTORS FROM THE FIRST LIGHT FIXTURE/LOAD TO THE BREAKER IN THE SOURCE PANEL.
13. ALL 277V, 20A CIRCUITS WITH HOMERUNS 151-250 FEET SHALL BE #8 CU. MINIMUM FOR HOMERUN (1"), WITH #10 FOR REMAINDER OF CIRCUIT UNLESS OTHERWISE NOTED (CONDUIT SIZE PER SPECIFICATION AND NEC). THE HOMERUN LENGTH IS THE LENGTH OF THE CIRCUIT CONDUCTORS FROM THE FIRST LIGHT FIXTURE/LOAD TO THE BREAKER IN THE SOURCE PANEL.
14. ALL 277V, 20A CIRCUITS WITH HOMERUNS 251-400 FEET SHALL BE #6 CU. MINIMUM FOR HOMERUN (1-1/4" C.), WITH #10 FOR REMAINDER OF CIRCUIT UNLESS OTHERWISE NOTED (CONDUIT SIZE PER SPECIFICATION AND NEC). THE HOMERUN LENGTH IS THE LENGTH OF THE CIRCUIT CONDUCTORS FROM THE FIRST LIGHT FIXTURE/LOAD TO THE BREAKER IN THE SOURCE PANEL.
15. COORDINATE EXACT LOCATIONS OF INSTALLATIONS AT SIGN WITH SIGN INSTALLER, MASON, CONCRETE FOREMAN, VCS PROJECT MANAGER, AND ARCHITECT PRIOR TO START OF WORK. INSTALLATIONS SHALL BE CONCEALED WHENEVER PRACTICAL.
16. VISIT AND CAREFULLY EXAMINE THOSE PORTIONS OF THE BUILDING AND SITE AFFECTED BY THIS WORK BEFORE SUBMITTING PROPOSALS, SO AS TO BECOME FAMILIAR WITH EXISTING CONDITIONS AND DIFFICULTIES THAT WILL AFFECT EXECUTION OF THE WORK. SUBMISSION OF A PROPOSAL WILL BE CONSTRUED AS EVIDENCE THAT SUCH EXAMINATION HAS BEEN MADE AND LATER CLAIMS FOR LABOR, EQUIPMENT OR MATERIALS REQUIRED BECAUSE OF DIFFICULTIES ENCOUNTERED WILL NOT BE RECOGNIZED.
17. READ SPECIFICATIONS.
18. SEE RISER DIAGRAMS AND BUILDING PLANS.
19. ALL EMPTY CONDUITS ARE TO HAVE PULL-STRINGS PROVIDED IN THEM.
20. WHERE CONDUIT ROUTING IS SHOWN, THE CONDUITS ARE SHOWN FOR DIAGRAMMATIC PURPOSES AND ARE NOT NECESSARILY REPRESENTATIVE OF EXACT PLACEMENT. THE ROUTINGS SHOWN ARE PROPOSED CONDUIT ROUTINGS. CONTRACTOR TO COORDINATE ALL ROUTING WITH OTHER TRADES PRIOR TO BID. CONTRACTOR TO FIELD VERIFY EXISTING CONDITIONS AND ROUTING OF CONDUIT PRIOR TO BID. CONTRACTOR IS RESPONSIBLE FOR RELOCATING CONDUIT FROM THE PROPOSED ROUTING SHOWN TO THE ROUTING REQUIRED TO FACILITATE INSTALLATION PER SPECIFICATIONS AND APPLICABLE CODES, COMPLETE WITH ALL COORDINATION AND EXISTING CONDITIONS TAKEN INTO ACCOUNT. CONTRACTOR IS RESPONSIBLE FOR ALL CEILING AND WALL REPAIR/REPLACEMENT AFTER ROUTING OF CONDUIT.
21. ALL CONDUIT TERMINATIONS AT TERMINAL BOARDS ARE TO HAVE BUSHED CONDUIT ENDS.
22. SPLICES IN POWER AND LIGHTING OUTLET BOXES SHALL BE KEPT TO A MINIMUM. PULL CONDUCTORS THROUGH TO DEVICES, EQUIPMENT CABINETS/PANELBOARDS. SPLICING IN WIREWAYS IS NOT PERMITTED UNLESS SPECIAL WRITTEN PERMISSION IS GRANTED BY A/E.
23. NO SPLICES SHALL BE MADE IN COMMUNICATIONS OUTLET BOXES OR PULL BOXES (E.E., FIRE ALARM, COMPUTER, TELEPHONE, ETC) UNLESS SPECIFIC WRITTEN APPROVAL HAS BEEN GIVEN BY ENGINEER. PULL CABLES THROUGH TO EQUIPMENT/TERMINAL CABINETS.
24. NO SPLICES SHALL BE MADE IN UNDERGROUND (OR FLUSH) IN-GRADE PULL BOXES UNLESS ENGINEER HAS GIVEN SPECIFIC ACCEPTANCE.
25. CONTRACTOR SHALL INCLUDE IN HIS BID THE TRANSPORT AND DISPOSAL OR RECYCLING OF ALL WASTE MATERIALS GENERATED BY THIS PROJECT IN ACCORDANCE WITH ALL RULES, REGULATIONS AND GUIDELINES APPLICABLE. CONTRACTOR SHALL COMPLY FULLY WITH FLORIDA STATUTE, 403.7168 REGARDING MERCURY CONTAINING DEVICES AND LAMPS. LAMPS, BALLASTS AND OTHER MATERIALS SHALL BE TRANSPORTED AND DISPOSED OF IN ACCORDANCE WITH ALL DEP AND EPA GUIDELINES APPLICABLE AT TIME OF DISPOSAL. CONTRACTOR SHALL PROVIDE OWNER WITH WRITTEN CERTIFICATION OF ACCEPTED DISPOSAL.
26. EXISTING CONDITIONS AND UTILITIES INDICATED ARE TAKEN FROM EXISTING CONSTRUCTION DOCUMENTS, VARIOUS SURVEYS, AND FIELD INVESTIGATIONS. IT IS TO BE UNDERSTOOD THAT UNFORESEEN CONDITIONS PROBABLY EXIST AND NEW WORK MAY NOT BE FIELD LOCATED EXACTLY AS SHOWN ON THE DRAWINGS. COOPERATION WITH OTHER TRADES IN ROUTING AND/OR BURIAL DEPTHS AS DETERMINED DURING CONSTRUCTION AND AS DIRECTED BY THE ARCHITECT/ENGINEER MAY BE NECESSARY AND IT IS INTENDED THAT SUCH DEVIATIONS SHALL BE CONSIDERED A PART OF THIS CONTRACT. IT IS ALSO UNDERSTOOD THAT THE PLANS ARE NOT COMPLETELY TO SCALE. THIS CONTRACTOR IS TO FIELD VERIFY DIMENSIONS OF ALL SITE UTILITIES, ETC., PRIOR TO BID AND INCLUDE ANY DEVIATIONS IN THE CONTRACT.
27. IT SHALL BE THE RESPONSIBILITY OF THE CONTRACTOR TO LOCATE ALL EXISTING UTILITIES WHETHER SHOWN ON PLANS OR NOT AND TO PROTECT THEM FROM DAMAGE. THE CONTRACTOR SHALL BEAR ALL EXPENSE FOR REPAIR OR REPLACEMENT OF UTILITIES OR OTHER PROPERTY DAMAGED BY OPERATIONS IN CONJUNCTION WITH THE COMPLETION OF THIS WORK. THE CONTRACTOR SHALL LOCATE ALL UTILITIES (BOTH KNOWN AND UNKNOWN) IN AREA OF WORK PRIOR TO EXCAVATION WITH THE USE OF ELECTRONIC LOCATION/TRACER DEVICES AND EQUIPMENT SUITABLE FOR SUCH USE. REFLECT LOCATED UTILITIES ON AS-BUILT DOCUMENTS.
28. REMOVE EXISTING POWER, LIGHTING, SYSTEMS, MATERIAL AND EQUIPMENT WHICH ARE MADE OBSOLETE OR WHICH INTERFERE WITH THE CONSTRUCTION OF THE PROJECT.
29. REINSTALL ANY SUCH POWER, LIGHTING, SYSTEMS, MATERIALS AND EQUIPMENT WHICH ARE REQUIRED TO REMAIN ACTIVE FOR THE FACILITY TO BE FULLY FUNCTIONAL.
30. ALL EXISTING ELECTRICAL IS NOT SHOWN. IT IS THE CONTRACTORS RESPONSIBILITY TO BECOME FAMILIAR WITH ALL EXISTING CONDITIONS PRIOR TO BID, AND INCLUDE IN HIS BID THE REMOVAL OF ALL ELECTRICAL EQUIPMENT, WIRE, CONDUIT, DEVICES, FIXTURES, ETC. THAT IS NOT BEING REUSED, BACK TO ITS SOURCE.
31. ALL RECEPTACLES, DEVICES AND EQUIPMENT NOT SHOWN, AND IN AREAS OUTSIDE OF REMODELING SHALL REMAIN ACTIVE UNLESS OTHERWISE NOTED. FURNISH AND INSTALL ACCESSIBLE JUNCTION BOXES AND REMARK EXISTING CIRCUITS AS REQUIRED TO MAINTAIN CIRCUIT CONTINUITY TO RECEPTACLES, DEVICES AND EQUIPMENT REMAINING.
32. ALL CONDUIT TO BE CONCEALED UNLESS IMPOSSIBLE DUE TO EXISTING CONDITIONS (I.E. EXPOSED CEILINGS, BUILDING EXTERIOR WALL RUNS, IMPOSSIBLE UNDERGROUND RUNS). CONCEAL ALL CONDUITS ABOVE CEILINGS OR IN WALL/COUNTERS.
33. ALL NEW DEVICES TO BE FLUSH MOUNTED UNLESS SPECIFICALLY NOTED OTHERWISE.
34. ELECTRICAL CONTRACTOR SHALL INCLUDE ALL EXISTING PANELBOARD SCHEDULES FOR PANELBOARDS ASSOCIATED WITH CONTRACT LIMITS WHETHER SHOWN ON PLANS OR NOT AS PART OF A COMPLETE AS-BUILT SET OF DRAWINGS. SCHEDULES SHALL SHOW FINAL CONFIGURATION, ETC. OF CIRCUITS, CIRCUIT BREAKERS, DIRECTORY, ETC.
35. ALL EXISTING BRANCH CIRCUITS AND FEEDERS (REMAINING ACTIVE) WHICH ARE CONNECTED TO EXISTING PANELBOARDS THAT ARE AFFECTED BY THIS CONTRACT, SHALL BE TRACED-OUT AND PROPERLY NOTED AND IDENTIFIED ON NEW PANEL DIRECTORIES.
36. ALL PANELS, CIRCUIT BREAKERS, JUNCTION BOXES, ETC. THAT ARE ASSOCIATED WITH PROJECT SHALL BE PROPERLY IDENTIFIED AS PER SPECIFICATIONS.
37. PROVIDE NEW TYPED PANEL DIRECTORIES FOR ALL EXISTING AND NEW PANELBOARDS FOR PANELBOARDS ASSOCIATED WITH CONTRACT WHETHER SHOWN ON PLANS OR NOT REGARDLESS IF SCHEDULES/CIRCUITRY HAS BEEN CHANGED.
38. PROVIDE NEW PHENOLIC LABELS (PER SPEC'S) ON ALL (2) TWO POLE AND (3) THREE POLE CIRCUIT BREAKERS WITHIN ALL EXISTING AND NEW PANELBOARDS ASSOCIATED WITH CONTRACT WHETHER SHOWN ON PLANS OR NOT REGARDLESS IF SCHEDULES/CIRCUITRY HAS BEEN CHANGED.
39. ALL EXISTING AND NEW CIRCUIT BREAKERS WITHIN EACH EXISTING PANELBOARD SHALL BE THE SAME MFG. TYPE, STYLE AND A.L.C. RATING OF EXISTING PANELBOARD REGARDLESS OF WHAT IS SHOWN ON PANEL SCHEDULE. FIELD VERIFY ALL EXISTING PANELBOARD(S) AND PROVIDE CIRCUIT BREAKERS AS NECESSARY TO COMPLY WITH THIS REQUIREMENT.
40. ALL CONCRETE, WALL PATCHING, CEILING REPAIR, WALL FINISHES, AND OTHER GENERAL WORK REQUIRED FOR INSTALLING ELECTRICAL SYSTEMS SHALL BE REPAIRED TO "LIKE NEW/ORIGINAL CONDITION." (COORDINATE WITH GENERAL CONTRACTOR PRIOR TO BID.)
41. ALL PATCHES OR CEILING PLANTS SHALL BE PATCHED OR PAINTED AS DIRECTED BY ARCHITECT.
42. PAINT ALL EXPOSED CONDUIT, BOXES, ETC. TO MATCH WALL SURFACE.
43. ALL OPENINGS IN FIRE RATED WALLS AND FLOORS, ETC. MADE BY RENOVATION SHALL BE SEALED AND FIREPROOFED. PROVIDE AND INSTALL FIRESTOPPING ON ALL NEW OR EXISTING CONDUIT AND/OR CABLE THAT PENETRATES ANY FIRE RATED NEW OR EXISTING WALL IN ALL AREAS AFFECTED BY THIS PROJECT. VERIFY LOCATION OF FIRE RATED WALLS WITH ARCHITECTURAL PLANS PRIOR TO BID. FIRESTOPPING SYSTEM SHALL AS BE REQUIRED BY UL FOR RATING OF WALL AND CONDUIT/CABLE PENETRATION.
44. DASHED LINES INDICATE EXISTING TO REMAIN.
45. "R" ADJACENT TO DEVICE INDICATES EXISTING TO BE REMOVED COMPLETE.
46. NEW UNDERGROUND RACEWAYS ARE TO BE HAND DUG. ROUTE UNDER EXISTING WALKWAYS AS REQUIRED BY OWNER.
47. ALL ITEMS REMOVED AND NOT RE-USED SHALL BE IMMEDIATELY TURNED OVER TO OWNER AS THEY ARE MADE AVAILABLE BY RENOVATION. REMOVE ITEMS FROM JOB SITE AND DELIVER TO OWNERS STORAGE LOCATION(S) AS DIRECTED BY PROJECT MANAGER. DISCARD COMPLETE ITEMS WHICH OWNER ELECTS TO REFUSE.
48. WORK TO BE PERFORMED IN STRICT COMPLIANCE WITH ESTABLISHED WORK SCHEDULE BEING SET FORTH BY OWNER/TENANT. COORDINATE ALL WORK. THE CONTRACTOR SHALL FURNISH ADEQUATE FORCES, CONSTRUCTION PLANT, AND EQUIPMENT, AND SHALL WORK SUCH HOURS INCLUDING NIGHT SHIFTS, OVERTIME OPERATIONS, SUNDAY, AND HOLIDAYS IN ACCORDANCE WITH THE OWNERS OPERATIONAL SCHEDULE. IF THE CONTRACTOR FALLS BEHIND PROGRESS REQUIRED IN THE OPERATIONAL SCHEDULE, THE CONTRACTOR SHALL TAKE SUCH STEPS AS MAY BE NECESSARY TO IMPROVE HIS PROGRESS, AND THE OWNER MAY REQUIRE HIM TO INCREASE THE NUMBER OF SHIFTS AND/OR OVERTIME OPERATIONS, DAY OF WORK AND/OR THE AMOUNT OF CONSTRUCTION PLANT, AT NO ADDITIONAL COST TO THE OWNER UNDER THIS CONTRACT. (IT SHALL BE UNDERSTOOD THAT SEVERAL BID PACKAGES MAY BE SUBMITTED BY VARIOUS CONTRACTOR/SUB-CONTRACTORS WITHIN THE SAME WORK SPACE CONJUNCTUOUSLY.)
49. USE OF MC CABLE IS NOT ACCEPTABLE.
50. MINIMUM CONDUIT SIZE IS 3/4" EXCEPT FOR FIXTURE WHIPS NOT

| SYMBOL LEGEND |                                                                                                                                                                                                      |                                                                                      |                                                                         |                                                                                        |                  |
|---------------|------------------------------------------------------------------------------------------------------------------------------------------------------------------------------------------------------|--------------------------------------------------------------------------------------|-------------------------------------------------------------------------|----------------------------------------------------------------------------------------|------------------|
| SYMBOL        | DESCRIPTION                                                                                                                                                                                          | DESIGN SELECTION                                                                     | APPROVED SUBSTITUTION                                                   | APPROVED SUBSTITUTION                                                                  | REMARKS          |
|               | POLE WITH MOUNTING ARM AND CUT-OFF LIGHT FIXTURE. BOXES INDICATE NUMBER OF FIXTURES AND ORIENTATION                                                                                                  | SEE FIXTURE SCHEDULE                                                                 |                                                                         |                                                                                        |                  |
|               | POLE WITH MOUNTING ARM AND FLOOD LIGHT FIXTURE. SEMI-CIRCLES INDICATE NUMBER OF FIXTURES AND ORIENTATION                                                                                             | SEE FIXTURE SCHEDULE                                                                 |                                                                         |                                                                                        |                  |
|               | POLE WITH YOKE/SPIDER MOUNTED CUT-OFF LIGHT FIXTURE                                                                                                                                                  | SEE FIXTURE SCHEDULE                                                                 |                                                                         |                                                                                        |                  |
|               | WALL OUTLET BOX AND 20 AMP SINGLE POLE SWITCH (# indicates SWITCH-LEG)                                                                                                                               | P&S #PS20AC1                                                                         | HUBBELL #HBL1221                                                        | LEVITON #1221-2                                                                        | d                |
|               | WALL OUTLET BOX AND 20 AMP DOUBLE POLE SWITCH                                                                                                                                                        | P&S #PS20AC2                                                                         | HUBBELL #HBL1222                                                        | LEVITON #1222-2                                                                        | d                |
|               | WALL OUTLET BOX AND 20 AMP THREE-WAY SWITCH                                                                                                                                                          | P&S #PS20AC3                                                                         | HUBBELL #HBL1223                                                        | LEVITON #1223-2                                                                        | d                |
|               | WALL OUTLET BOX AND 20 AMP FOUR-WAY SWITCH                                                                                                                                                           | P&S #PS20AC4                                                                         | HUBBELL #HBL1224                                                        | LEVITON #1224-2                                                                        | d                |
|               | WALL OUTLET BOX AND SECURITY LOCKING KEY SWITCH, 20 AMP, SINGLE POLE, WITH S.S. PLATE, PROVIDE TWO KEYS                                                                                              | P&S #PS20AC1-KL-55-717                                                               | DEVICE: HUBBELL HBL1221RKL<br>PLATE: S12RKL                             |                                                                                        | d                |
|               | FLUSH WALL OUTLET BOX AND 20 AMP SINGLE POLE SWITCH, WITH DIE CAST WEATHERPROOF COVER                                                                                                                | DEVICE: P&S #PS20AC1<br>PLATE: P&S #CA1-G                                            | DEVICE: HUBBELL #HBL1221<br>PLATE: P&S #CA1-G                           | DEVICE: LEVITON #1221-2                                                                | a, d             |
|               | FLUSH WALL OUTLET BOX AND 20 AMP SINGLE POLE SWITCH, WITH LOCKING STAINLESS STEEL WEATHERPROOF COVER. MOUNT OUTLET BOX HORIZONTALLY.                                                                 | DEVICE: P&S #20AC1<br>PLATE: P&S #WPH-1L                                             | DEVICE: HUBBELL #HBL1221<br>PLATE: P&S #WPH-1L                          | DEVICE: LEVITON #1221-2                                                                | a, d             |
|               | CAST IRON ZINC PLATED SURFACE MTD. OUTLET BOX WITH CAST ALUMINUM WEATHERPROOF COVER                                                                                                                  | DEVICE: P&S #PS20AC1<br>BOX AND PLATE: APPLETON #FS/ED/FSK-WT2                       | DEVICE: HUBBELL #HBL1221<br>BOX AND PLATE: APPLETON #FS/ED/FSK-WT2      | DEVICE: LEVITON #1221-2                                                                | a, d, e, f, g    |
|               | WALL OUTLET BOX WITH 20 AMP SELF-TESTING GFCI DUPLEX RECEPTACLE                                                                                                                                      | P&S #2097TRGRY                                                                       | HUBBELL #GFR5352GYST                                                    | LEVITON #S7899-GY                                                                      | d                |
|               | FLUSH WALL OUTLET BOX AND 20 AMP WEATHER RESISTANT SELF-TESTING GFCI DUPLEX RECEPTACLE WITH CAST ALUMINUM WEATHER PROOF IN USE COVER                                                                 | P&S #2095TRWR WITH THOMAS & BETTS #CKMUV OR INTERMATIC #WP10TOMC                     | HUBBELL #GFR5362S WITH THOMAS & BETTS #CKMUV OR INTERMATIC #WP20M COVER | LEVITON #W7899-TR WITH THOMAS & BETTS #CKMUV OR INTERMATIC #WP10TOMC                   | a, d             |
|               | CAST IRON PLATED SURFACE MTD. OUTLET BOX AND 20 AMP WEATHER RESISTANT GFCI DUPLEX RECEPTACLE WITH CAST ALUMINUM WEATHERPROOF IN USE COVER                                                            | P&S #2095TRWR WITH APPLETON #FS-ID AND THOMAS & BETTS #CKMUV OR INTERMATIC #WP10TOMC | HUBBELL #GFR5362S<br>APPLETON #FS-ID AND HUBBELL #WP20M COVER           | LEVITON #W7899-TR<br>APPLETON #FS-ID AND THOMAS & BETTS #CKMUV OR INTERMATIC #WP10TOMC | a, c, d, e, f, g |
|               | FLUSH WALL JUNCTION BOX AND BLANK PLATE                                                                                                                                                              | STEEL CITY                                                                           | RACO                                                                    |                                                                                        | d                |
|               | JUNCTION BOX AND BLANK PLATE ABOVE CEILING                                                                                                                                                           | STEEL CITY                                                                           | RACO                                                                    |                                                                                        | b,d              |
|               | SURFACE JUNCTION BOX AND BLANK PLATE, WALL MTD. OR MTD. TO CEILING/STRUCTURE AS INDICATED                                                                                                            | STEEL CITY                                                                           | RACO                                                                    |                                                                                        | b, d, g, h       |
|               | SURFACE MTD. WEATHERPROOF JUNCTION BOX AND COVER, AS NOTED ON PLANS                                                                                                                                  | HOFFMAN                                                                              |                                                                         |                                                                                        | d, g, h          |
|               | CAST IRON ZINC PLATED SURFACE MTD. OUTLET BOX AND WEATHERPROOF BLANK PLATE                                                                                                                           | APPLETON #FS-ID WITH #US-100G COVER                                                  |                                                                         |                                                                                        | a, d, e, f, g, h |
|               | FLUSH GRADE PULLBOX OR MANHOLE AS NOTED.                                                                                                                                                             | BROOKS                                                                               | A.C. MILLER                                                             | HUGHES                                                                                 | d, j             |
|               | TIME CLOCK, 2-POLE, RESERVE SPRING, 24 HR. WITH CONTACTS AND COIL VOLTAGE AS REQUIRED FOR CIRCUITS (UNLESS OTHERWISE NOTED)                                                                          | TORK (SEE DETAIL)                                                                    | PARAGON (SEE DETAIL)                                                    | INTERMATIC (SEE DETAIL)                                                                | i                |
|               | PHOTO CELL                                                                                                                                                                                           | TORK (SEE DETAIL)                                                                    | PARAGON (SEE DETAIL)                                                    | INTERMATIC (SEE DETAIL)                                                                |                  |
|               | BUSBAR                                                                                                                                                                                               |                                                                                      |                                                                         |                                                                                        |                  |
|               | MAGNETIC MOTOR STARTER, MOTOR CONTROLLER OR CONTACTOR, AS NOTED                                                                                                                                      | SQUARE "D"                                                                           | G.E.                                                                    | SIEMENS                                                                                | g, i             |
|               | DISCONNECT SWITCH, SIZE AS NOTED                                                                                                                                                                     | SQUARE "D"                                                                           | G.E.                                                                    | SIEMENS                                                                                | g, i             |
|               | 120/208V BRANCH CIRCUIT PANELBOARD SURFACE MOUNTED                                                                                                                                                   | SQUARE "D"                                                                           | G.E.                                                                    | SIEMENS                                                                                | i                |
|               | 120/208V BRANCH CIRCUIT PANELBOARD FLUSH MOUNTED                                                                                                                                                     | SQUARE "D"                                                                           | G.E.                                                                    | SIEMENS                                                                                | i                |
|               | 277/480V BRANCH CIRCUIT PANELBOARD SURFACE MOUNTED                                                                                                                                                   | SQUARE "D"                                                                           | G.E.                                                                    | SIEMENS                                                                                | i                |
|               | 277/480V BRANCH CIRCUIT PANELBOARD FLUSH MOUNTED                                                                                                                                                     | SQUARE "D"                                                                           | G.E.                                                                    | SIEMENS                                                                                | i                |
|               | TRANSFORMER                                                                                                                                                                                          | SQUARE "D"                                                                           | G.E.                                                                    | SIEMENS                                                                                | i                |
|               | AUTOMATIC TRANSFER SWITCH                                                                                                                                                                            | RUSSELECTRIC                                                                         | ASCO                                                                    |                                                                                        | i                |
|               | SYSTEMS PANEL - SURFACE MOUNTED                                                                                                                                                                      | SEE SYSTEMS LEGEND/SPECS                                                             |                                                                         |                                                                                        | i, j             |
|               | SYSTEMS PANEL - FLUSH MOUNTED                                                                                                                                                                        | SEE SYSTEMS LEGEND/SPECS                                                             |                                                                         |                                                                                        | i, j             |
|               | SYSTEMS TERMINAL BOARD AS NOTED                                                                                                                                                                      | SEE SYSTEMS LEGEND/SPECS                                                             |                                                                         |                                                                                        |                  |
|               | BRANCH CIRCUIT CONDUIT CONCEALED ABOVE CEILING OR IN WALL. SLASH MARKS INDICATE NUMBER OF CONDUCTORS (GROUND WIRE NOT SHOWN). TWO CONDUCTORS PLUS GROUND REQUIRED (UNLESS OTHERWISE NOTED OR MARKED) |                                                                                      |                                                                         |                                                                                        |                  |
|               | BRANCH CIRCUIT CONDUIT CONCEALED BELOW SLAB OR UNDERGROUND                                                                                                                                           |                                                                                      |                                                                         |                                                                                        |                  |
|               | BRANCH CIRCUIT CONDUIT EXPOSED                                                                                                                                                                       |                                                                                      |                                                                         |                                                                                        |                  |
|               | HOME RUN WIRING. ONE CIRCUIT PER ARROW HEAD                                                                                                                                                          |                                                                                      |                                                                         |                                                                                        |                  |
|               | CONDUIT CAPPED OFF                                                                                                                                                                                   |                                                                                      |                                                                         |                                                                                        |                  |
|               | CONDUIT CONTINUED                                                                                                                                                                                    |                                                                                      |                                                                         |                                                                                        |                  |
|               | CONDUIT RUN UP                                                                                                                                                                                       |                                                                                      |                                                                         |                                                                                        |                  |
|               | CONDUIT RUN DOWN                                                                                                                                                                                     |                                                                                      |                                                                         |                                                                                        |                  |
|               | CONDUIT SEAL-OFF FITTING                                                                                                                                                                             | CROUSE HINDS                                                                         | APPLETON                                                                |                                                                                        | e                |
|               | GROUND WIRE, CONCEALED                                                                                                                                                                               |                                                                                      |                                                                         |                                                                                        |                  |
|               | GROUND OR GROUND ROD AS NOTED                                                                                                                                                                        |                                                                                      |                                                                         |                                                                                        |                  |

| <u>ELECTRICAL SHEET INDEX</u> |                                          |              |
|-------------------------------|------------------------------------------|--------------|
| <u>SHEET NO.</u>              | <u>SHEET NAME</u>                        | <u>SCALE</u> |
| E001                          | GENERAL NOTES AND LEGENDS - ELECTRICAL   | NONE         |
| E100                          | PARTIAL SITE PLAN - ELECTRICAL           | 1" = 20'-0"  |
| E101                          | SIGNAGE PLANS AND ELEVATIONS -ELECTRICAL | 1/2" = 1'-0" |
| E501                          | DETAILS - ELECTRICAL                     | A3 NOTED     |

**NOTES:**

- 1) ALL DEVICES TO BE GREY WITH SMOOTH METAL #302 S.S. PLATES UNLESS OTHERWISE NOTED.
  - 2) DASHED ITEM DENOTES "EXISTING".
  - 3) "R" BY DEVICE DENOTES EXISTING TO BE REMOVED COMPLETELY.
  - 4) "H" BY DEVICE DENOTES DEVICE TO BE MOUNTED HORIZONTALLY.
  - 5) MOUNT SWITCHES AT 48" AFF TO TOP.
  - 6) SEE SPECIFICATIONS FOR ADDITIONAL REQUIREMENTS.
  - 7) ALL ITEMS NOTED ON THE LEGENDS DO NOT NECESSARILY APPEAR ON PLANS.
- REMARKS:
- a) U.L. LISTED FOR WET LOCATION IN CLOSED POSITION.
  - b) SUPPORT OUTLET BOX FROM STRUCTURE WITH (1) 3/8" ALL THREADS MINIMUM. BOXES LARGER THAN 2 SQUARE INCHES SHALL BE SUPPORTED WITH (2) 3/8" ALL THREADS MINIMUM.
  - c) U.L. LISTED FOR WET LOCATION IN OPEN POSITION WITH ATTACHMENT PLUG INSERTED.
  - d) JUNCTION/OUTLET BOX SHALL BE SIZED AS REQUIRED FOR CONDUCTOR/DEVICE FILL PER N.E.C.
  - e) THREADED CONDUIT HUBS SHALL BE SIZED AND CONFIGURED AS REQUIRED FOR APPLICATION.
  - f) IF WITHIN 30 FEET OF THE COAST LINE, COPPER FREE CAST ALUMINUM OUTLET BOXES SHALL BE USED FOR EXTERIOR APPLICATIONS.
  - g) PROVIDE KINDORF MFG. RACK FOR FREE STANDING APPLICATIONS. KINDORF SHALL BE PVC COATED FOR EXTERIOR APPLICATIONS. ALL CUT ENDS ARE TO BE SEALED.
  - h) WHEN SURFACE JUNCTION BOX SYMBOL IS COMBINED WITH SYMBOL, PROVIDE APPROPRIATE SURFACE PLATE FOR OUTLET APPLICATION.
  - i) MAINTAIN WORKING CLEARANCES IN STRICT ACCORDANCE WITH N.E.C. COORDINATE EXACT LOCATION OF EQUIPMENT WITH ALL DISCIPLINES (I.E. STRUCTURAL, HVAC, PLUMBING, FIRE PROTECTION, KITCHEN, MILLWORK, ETC.) PRIOR TO ROUGH-IN TO MAINTAIN CLEARANCES.
  - j) OUTLET BOX SHALL BE SIZED PER SYSTEM INSTALLER REQUIREMENTS.

[illegible]HERITAGE MIDDLE  
DIGITAL MARQUEE

VCS Project NO. 2648217

1001 PARNELL CT. DELTONA, FLORIDA

|                                                             |                           |
|-------------------------------------------------------------|---------------------------|
| ARCHITECT OF RECORD                                         |                           |
| ENGINEER<br>Adrian Baas                                     |                           |
| DESIGNED BY<br>AWB                                          | DRAWN BY<br>MM/AWB        |
| ISSUE DATE<br>01/28/2026                                    | AE PROJECT NUMBER<br>2517 |
| SHEET TITLE<br>GENERAL NOTES<br>AND LEGENDS -<br>ELECTRICAL |                           |
| DRAWING NO.<br>E001                                         |                           |


**MATERN**

Mechanical • Electrical • Plumbing • Fire Protection  
Technology • Commissioning • Energy Engineers

**130 Candace Drive  
Maitland, FL 32751**

ENG. BUS. NO. EB-0005096      PHONE (407) 740-5020  
CERT. OF AUTH. NO. 5096      FAX (407) 740-0365

MPE JOB #: 2025-136

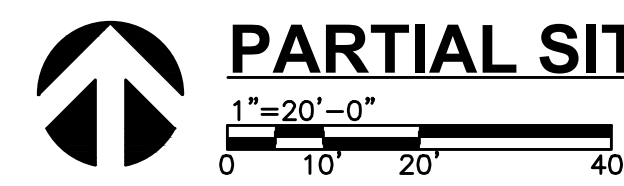

**MATERN**

Mechanical • Electrical • Plumbing • Fire Protection  
Technology • Commissioning • Energy Engineers

**130 Candace Drive  
Maitland, FL 32751**

ENG. BUS. No. EB-0005096      PHONE (407) 740-5020  
CERT. OF AUTH. No. 5096      FAX (407) 740-0365

MFE JOB #: 2025-136

- [illegible]

HERITAGE MIDDLE  
DIGITAL MARQUEE  
VCS Project NO. 2648217  
1001 PARNELL CT. DELTONA, FLORIDA




**HALL & OGLE  
ARCHITECTS, INC.**

208 MAGNOLIA AVENUE  
DAYTONA BEACH, FLORIDA 32114  
www.hoarchitects.com



PH (386) 255-6163  
FAX (386) 257-5650  
AA-C000925

|                                                          |                                  |                     |
|----------------------------------------------------------|----------------------------------|---------------------|
| <b>Engineer</b><br><b>Adrian Baus</b>                    |                                  | ARCHENGER OF RECORD |
| DESIGNED BY<br><b>AWB</b>                                | DRAWN BY<br><b>MMB/AWB</b>       |                     |
| ISSUE DATE<br><b>01/28/2026</b>                          | AE PROJECT NUMBER<br><b>2517</b> |                     |
| SHEET TITLE<br><b>PARTIAL SITE PLAN<br/>- ELECTRICAL</b> |                                  |                     |
| DRAWING NO.<br><b>E100</b>                               |                                  |                     |

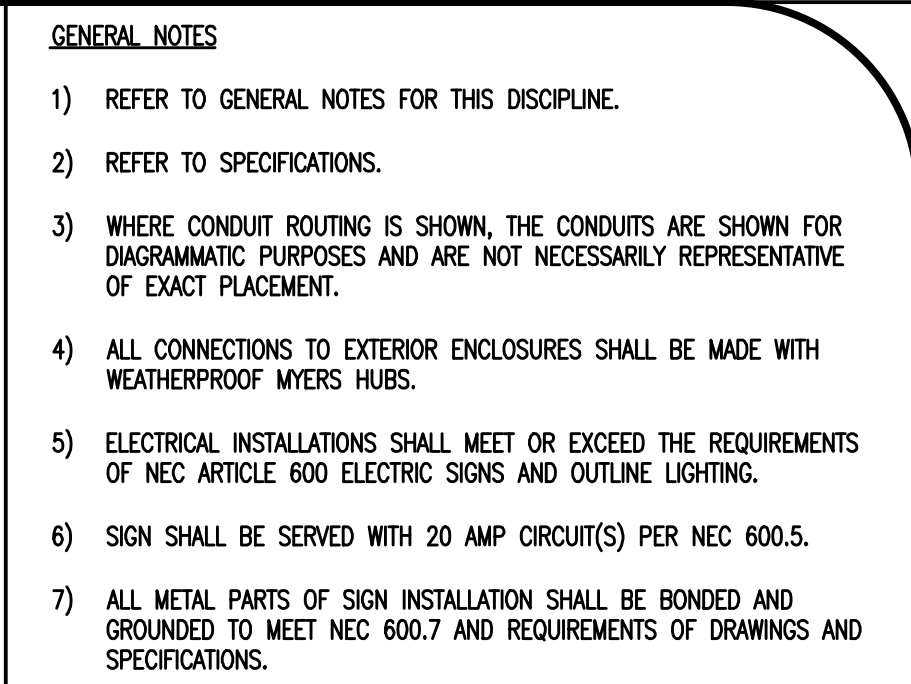

- ① PROVIDE 120/208 3 POLE FEED TO SIGN CONSISTING OF (4) #4 THWN-2 AND (1) #4 THWN-2 GROUND IN 1-1/2" CONDUIT.
- ② PROVIDE 3 POLE 60 AMP 120/208 VOLT NON-FUSED DISCONNECT WITH SN. DISCONNECT TO BE NEMA 3R. PROVIDE SURGE PROTECTION DEVICE (ASCO MODEL 420-120Y-P05-N-W-S-J-1-0 OR EQUAL BY SIEMENS) AT LOAD SIDE OF DISCONNECT. DISCONNECT AND SURGE PROTECTION DEVICE TO BE MOUNTED INSIDE SECONDARY ENCLOSURE. CONFIRM MOUNTING INSIDE SECONDARY ENCLOSURE. PRIOR TO ROUGH-IN.
- ③ PROVIDE 1-1/2" SPARE CONDUIT WITH PULL STRING FROM SIGN TO EXISTING MDF IN BUILDING 1. PROVIDE CAP ON END IN SIGN.
- ④ PROVIDE #4 OR LARGER COPPER GROUND WIRE TO (1) 5/8" BY 60"-0" (MIN) GROUND ROD.
- ⑤ PROVIDE #4 OR LARGER COPPER GROUND WIRE TO REINFORCING STEEL IN SIGN FOUNDATION.
- ⑥ PROVIDE 1" CONDUIT FROM DISCONNECT TO SIGN. COORDINATE WITH SIGN FABRICATOR THE PLACEMENT AND CONFIGURATION OF FEED FROM DISCONNECT TO SIGN. PROVIDE THREE 120 VOLT CIRCUITS WITH DEDICATED NEUTRALS. TWO CIRCUITS SHALL BE FOR THE LED SCREENS AND ONE CIRCUIT SHALL BE FOR THE SIGN CABINET.
- ⑦ PROVIDE 24"x24"x10" NEMA 4S 316L HINGED DOOR ENCLOSURE WITH 3 POINT PAD LOCKABLE LATCH (HOFFMAN A24H2010SSBL3PT WITH A24P20 MOUNTING PLATE). MOUNT DISCONNECT AND SURGE SUPPRESSION UNIT INSIDE ENCLOSURE. INCREASE DIMENSIONS OF ENCLOSURE IF NEEDED TO ACCOMMODATE DISCONNECT AND SURGE SUPPRESSION UNIT. ALL WIRING WITHIN ENCLOSURE SHALL BE IN SEAL TIGHT. INTENT OF PROVIDING THIS ENCLOSURE IS TO PROVIDE AN ADDITIONAL LOCKED MEANS TO KEEP STUDENTS AWAY FROM THE DISCONNECT SWITCH. CONFIRM MOUNTING ON SIGN MASONRY STRUCTURE WITH ARCHITECT PRIOR TO ROUGH-IN.

[illegible]

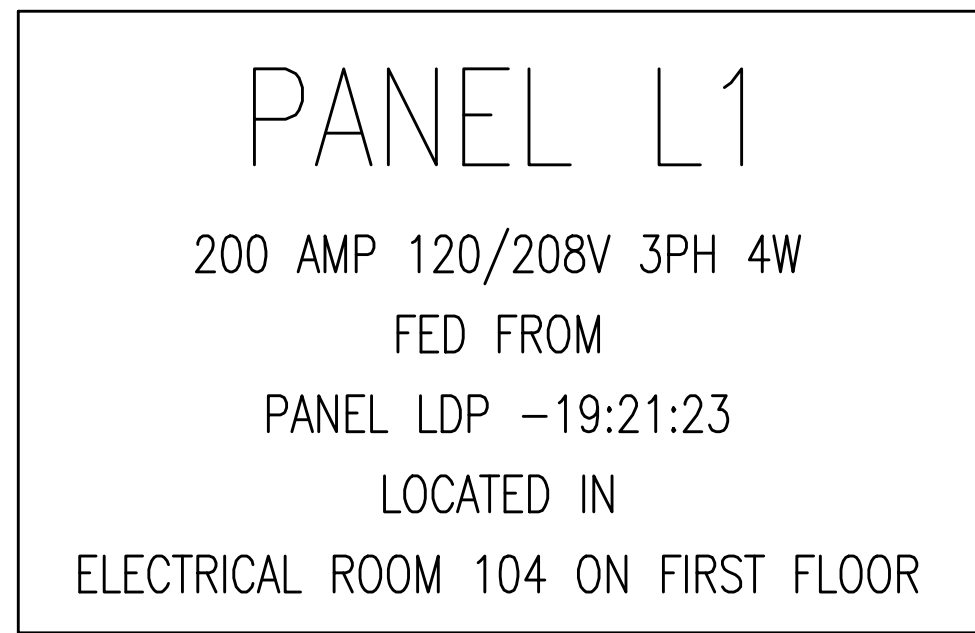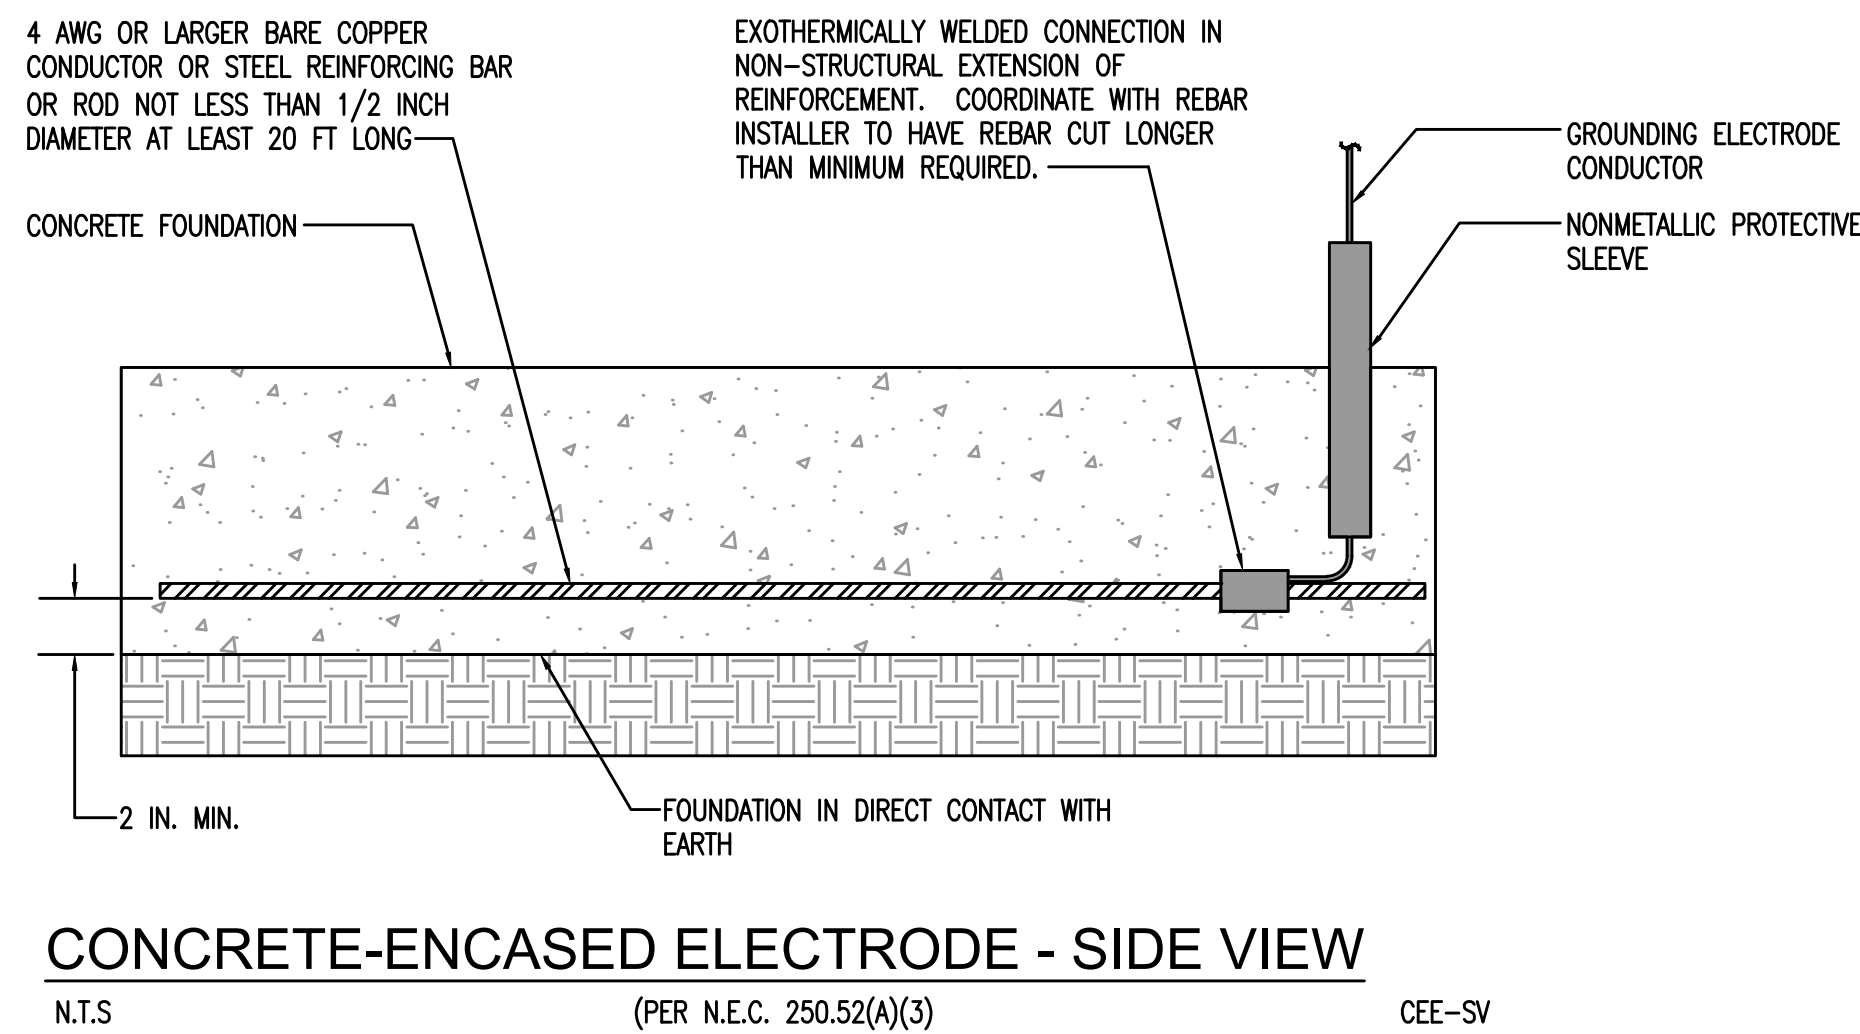

LAMACOID WITH WHITE CORE


## TYPICAL EQUIPMENT NAMEPLATES

N.T.S

GENERAL NOTES:

1. EQUIPMENT NAMEPLATES SHALL BE PROVIDED FOR ALL LOADS.
2. NAMEPLATES SHALL COMPLY WITH NEC REQUIREMENTS AND CLEARLY IDENTIFY THE LOAD SERVED, THE SOURCE AND THE LOCATION OF THE SOURCE.
3. NAMEPLATES FACE COLORS SHALL BE CONSISTENT WITH BUILDING STANDARD FOR SYSTEM/BRANCH. PROVIDE WHITE CORE FOR WHITE LETTERS.
4. NAMEPLATES FOR EQUIPMENT ON A GENERATOR SYSTEM BRANCH SHALL CLEARLY STATE THE ASSOCIATED BRANCH (LIFE SAFETY, CRITICAL OR EQUIPMENT).


| DEVICE                                                                        | DESIGN SELECTION      | APPROVED SUBSTITUTE          | APPROVED SUBSTITUTE          | VOLTAGE   | #CONTACTS REQ. |
|-------------------------------------------------------------------------------|-----------------------|------------------------------|------------------------------|-----------|----------------|
| PHOTOCELL                                                                     | TORK #2101 (2104)     | PARAGON #CW201-00 (CW201-27) | INTERMATIC #K4121M (K123M)   | 120V(277) | -----          |
| TIME CLOCK                                                                    | TORK #W220L (W222L)   | PARAGON #7218-00 (7218-27)   | INTERMATIC #T7801BC (7802BC) | 120V(277) | 2-N.O. 2-N.C.  |
| HOA SEL. SW.                                                                  | SQ."D" #KS43B 8 #KA-1 | G.E. #CR2940UB202B           | ALLEN BRADLEY #800TT-J2A     | 600V MAX. | 1-N.O. 1-N.C.  |
|                                                                               |                       |                              |                              |           |                |
| ( ) INDICATES CAT # FOR 277V. SELECT DEVICE TO MATCH CONTROL CIRCUIT VOLTAGE. |                       |                              |                              |           |                |
|                                                                               |                       |                              |                              |           |                |

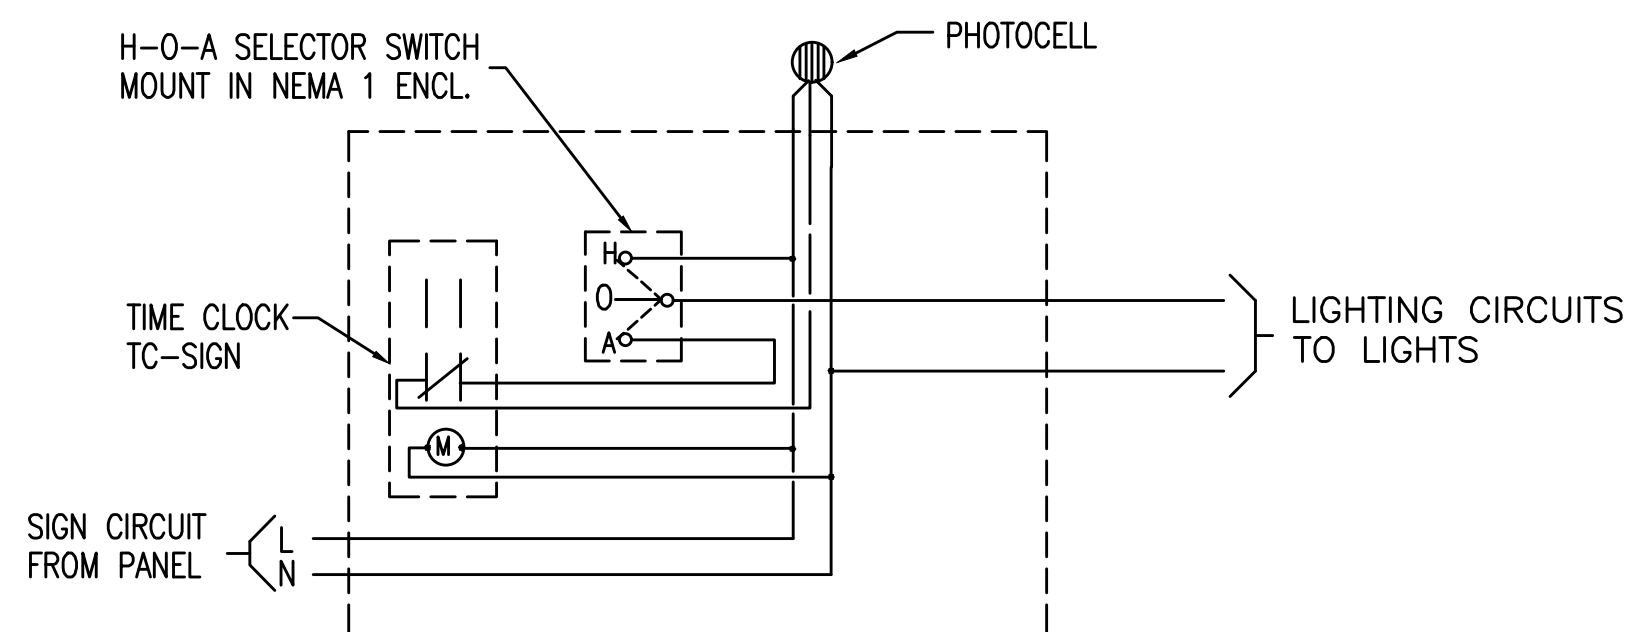

### LIGHTING CONTROL SCHEMATIC (SIGN) - PHOTOCELL 'ON', TIMECLOCK 'OFF'

N.T.S.

LCS4

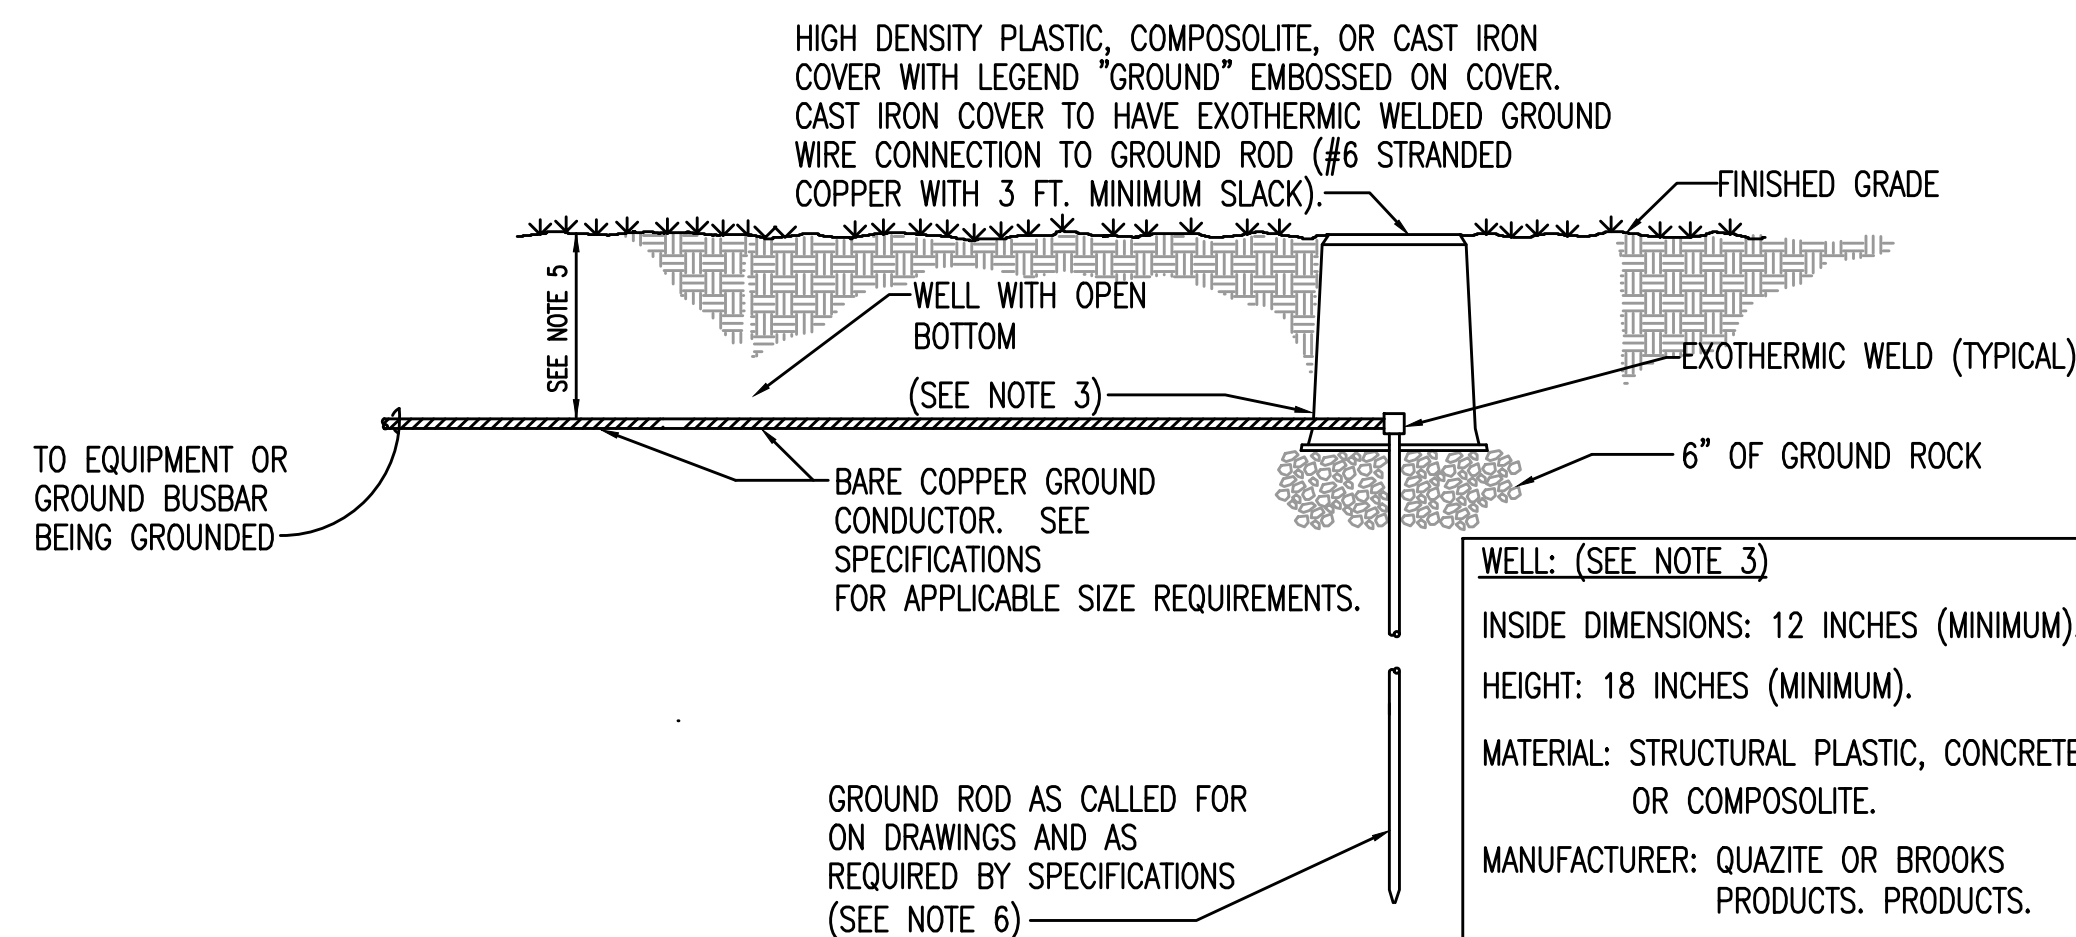

NOTES:

- 1) SEE SPECIFICATIONS
- 2) NOT FOR USE IN PAVED, ETC. LOCATIONS.
- 3) INCREASE DEPTH, DIAMETER, SIZE, ETC.  
IF REQUIRED DUE TO INSTALLATION AND  
ACCESS REQUIREMENTS.
- 4) CONCRETE COVERS ARE NOT ACCEPTABLE.
- 5) DEPTH PER CODES, 1'-0" MINIMUM.
- 6) PROVIDE ADDITIONAL GROUNDING ELECTRODES  
AS REQUIRED FOR SPECIFIED RESISTANCE.  
SPACING BETWEEN RODS SHALL BE EQUAL  
OR GREATER THAN LENGTH OF GROUND ROD.
- 7) MEASUREMENT OF RESISTANCE VALUES TO  
PROVE COMPLIANCE WITH SPECIFIED  
RESISTANCE SHALL BE WITH GROUND RODS  
CONNECTED TOGETHER BUT DISCONNECTED  
FROM EQUIPMENT OR BUSBAR BEING  
GROUNDED.

## GROUND WELL DETAIL FOR GRASSY UNPAVED NON-TRAFFIC AREAS

N.T.S.

GNDWEL1

REV. 8/16/06

[illegible]

HERITAGE MIDDLE  
DIGITAL MARQUEE  
VCS Project NO. 2648217  
1001 PARNELL CT. DELTONA, FLORIDA

|                                     |  |                           |  |
|-------------------------------------|--|---------------------------|--|
| Engineer<br>Adrian Baus             |  | ARCHENGR OF RECORD        |  |
| DESIGNED BY<br>AWB                  |  | DRAWN BY<br>MMW/ABW       |  |
| ISSUE DATE<br>01/28/2026            |  | AE PROJECT NUMBER<br>2517 |  |
| SHEET TITLE<br>DETAILS - ELECTRICAL |  |                           |  |
| DRAWING NO.                         |  |                           |  |
| E501                                |  |                           |  |