


C:\Users\allock\Documents\6241_SSP_USD Skyline ES HVAC_R22_Central_Abbreviations.rvt 2/18/2026 2:47:10 PM



FEMA FLOOD MAP

National Flood Hazard Layer FIRMette

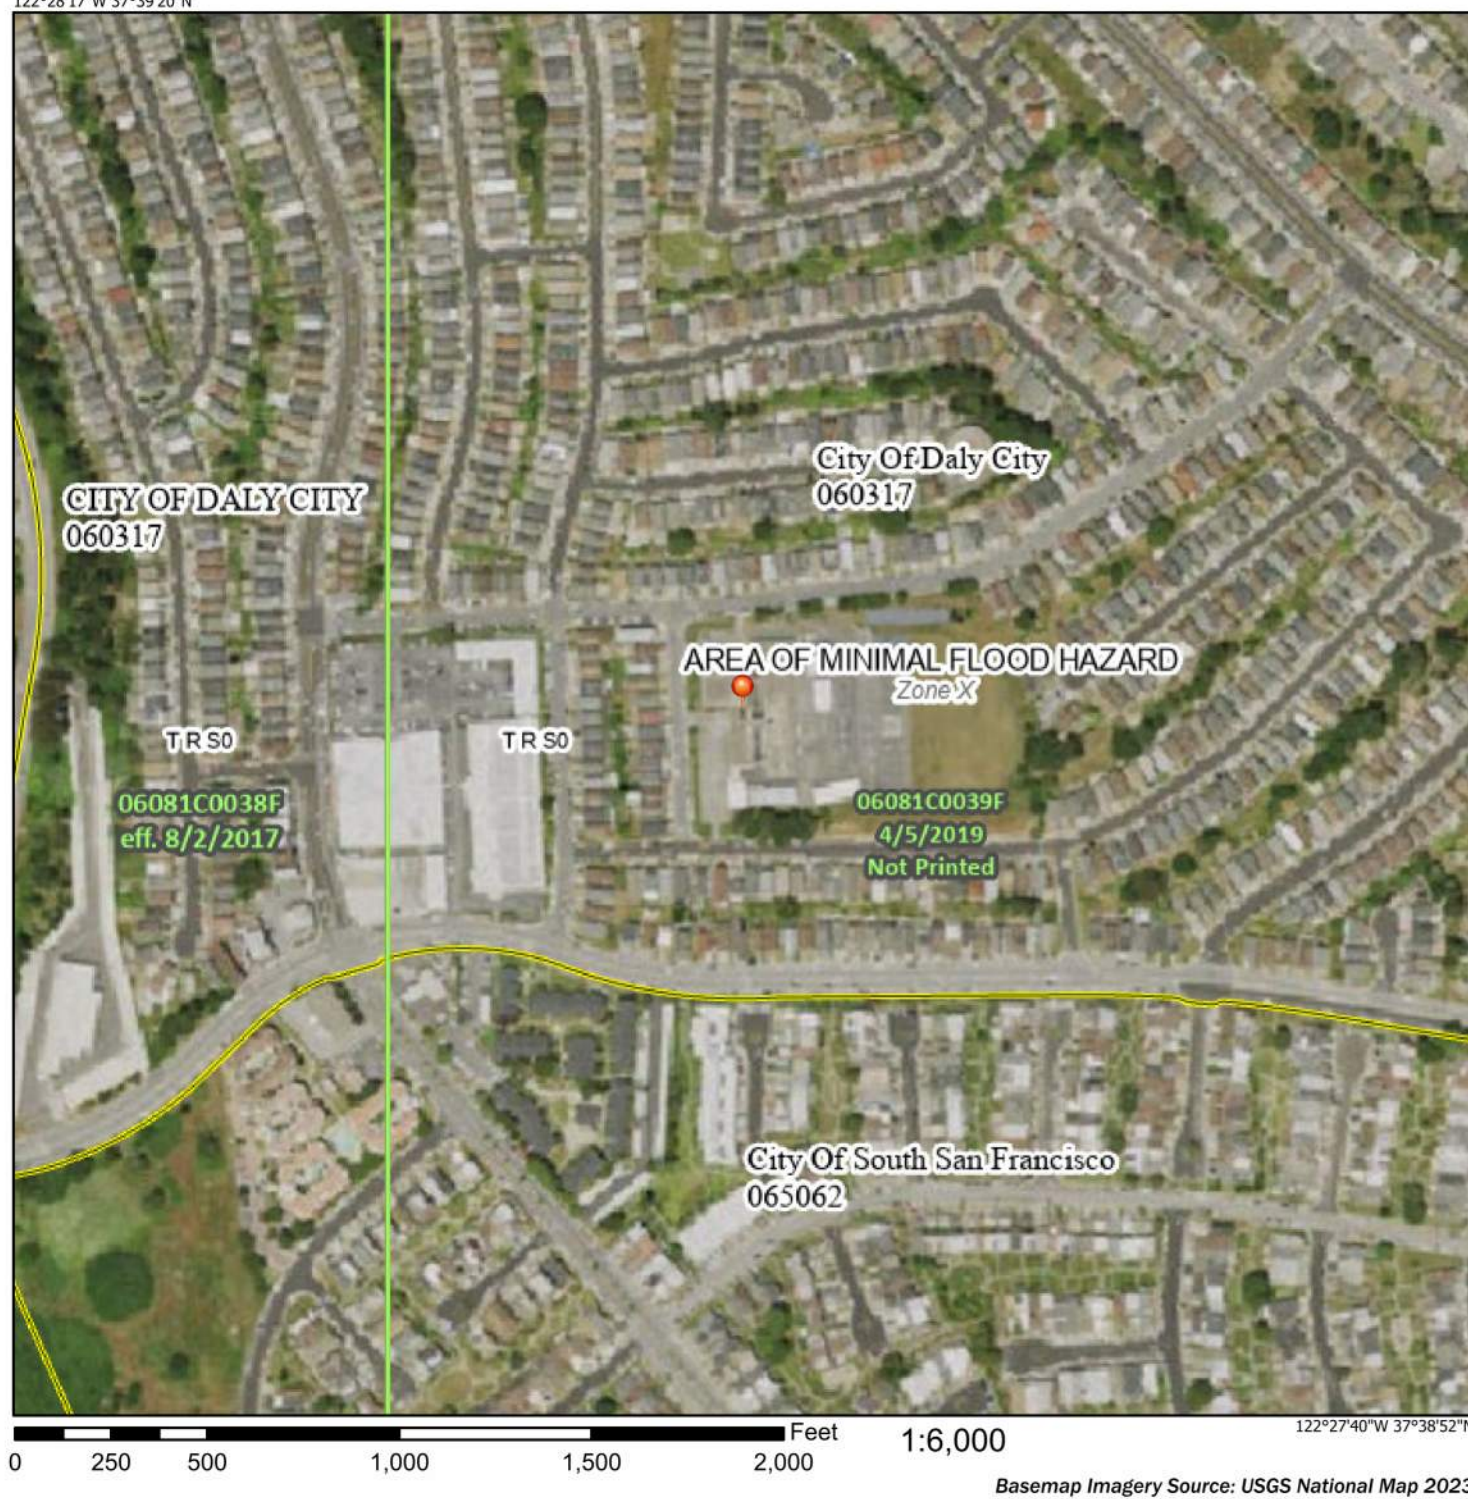


Legend	
SEE FS REPORT FOR DETAILED LEGEND AND INDEX MAP FOR FIRM PANEL LAYOUT	
SPECIAL FLOOD HAZARD AREAS	Without Base Flood Elevation (BFE) With BFE or Depth Zone AE, AH, AO, VE, VE1, VE2, VE3
OTHER AREAS OF FLOOD HAZARD	0.2% Annual Chance Flood Hazard, Areas of 1% annual chance flood with average depth less than one foot or with drainage areas of less than one square mile Zone X Future Conditions 1% Annual Chance Flood Hazard Zone F Area with Reduced Flood Risk due to Levee, See Notes, Zone D Area with Flood Risk due to Levee Zone D
OTHER AREAS	NO SCREEN Area of Minimal Flood Hazard Zone X Effective LOWMs Area of Undetermined Flood Hazard Zone D
GENERAL STRUCTURES	Channel, Culvert, or Storm Sewer Levee, Dike, or Floodwall
OTHER FEATURES	Cross Sections with 1% Annual Chance Water Surface Elevation Coastal Transect Base Flood Elevation Line (BFE) Limit of Study Jurisdiction Boundary Coastal Transect Baseline Profile Baseline Topographic Feature
MAP PANELS	Digital Data Available No Digital Data Available Unmapped
The pin displayed on the map is an approximate point selected by the user and does not represent an authoritative property location.	
This map complies with FEMA's standards for the use of digital flood maps. If it is not valid as described below, The basemap shown complies with FEMA's basemap accuracy standards.	
The flood hazard information is derived directly from the authoritative NFHL, web services provided by FEMA. This map was exported on 7/25/2025 at 9:18 PM, and does not reflect changes or amendments subsequent to this date and time. The NFHL and effective information may change or become superseded by new data over time.	
This map image is valid if the area or areas of the following map elements do not appear: basemap imagery, flood zone labels, legend, scale bar, map creation date, community identifier, FIRM panel number, and FIRM effective date. Map images for unimproved and unimproved areas cannot be used for regulatory purposes.	

ABBREVIATIONS


&	AND	S	SOUTH
@	AT	SC	SOLID CORE
Ø	CENTERLINE	SCD	SEE CIVIL DRAWINGS
Ø	DIAMETER	SCHED	SCHEDULE
#	POUND OR NUMBER	SD	SOAP DISPENSER
A/C	AIR CONDITIONING	SED	SEE ELECTRICAL DRAWINGS
AC	ASPHALTIC CONCRETE	SF	SQUARE FEET
ACOUS	ACOUSTICAL	SFPD	SEE FIRE PROTECTION DRAWINGS
ACT	ACOUSTIC CEILING TILE	SHT	SHEET
AD	ADDITIONAL	SLD	SEE LANDSCAPE DRAWINGS
ADJ	ADJACENT	SMD	SEE MECHANICAL DRAWINGS
AFF	ABOVE FINISHED FLOOR	SMS	SHEET METAL SCREW
ALT	ALTERNATE	SND	SANITARY NAPKIN DISPENSER
ALUM	ALUMINUM	SPD	SEE PLUMBING DRAWINGS
ANOD	ANODIZED	SPEC	SPECIFICATION
APPROX	APPROXIMATE	SQ	SQUARE
ARCH	ARCHITECTURAL	SS	STAINLESS STEEL
BITUM	BITUMINOUS	SSD	SEE STRUCTURAL DRAWINGS
BD	BOARD	STD	STANDARD
BLDG	BUILDING	STL	STEEL
BLKG	BLOCKING	STOR	STORAGE
BOT	BOTTOM	STRUC	STRUCTURAL
BTWN	BETWEEN	SUSP	SUSPEND
BUR	BUILT-UP ROOFING	TEL	TELEPHONE
CAB	CABINET	TEMP	TEMPORARY
CB	CATCH BASIN	THK	THICK
CFCI	CONTRACTOR FURNISHED CONTRACTOR INSTALLED	T.O.	TOP OF
CG	CORNER GUARD	TCC	TOP OF CURB
CJ	CONTROL JOINT	TOP	TOP OF PARAPET
CLG	CEILING	TOS	TOP OF SLAB
CLO	CLOSET	TOW	TOP OF WALL
CLR	CLEAR	TPD	TOILET PAPER DISPENSER
CMU	CONCRETE MASONRY UNIT	TV	TELEVISION
CO	CLEAN OUT	TYP	TYPICAL
COL	COLUMN	UON	UNLESS OTHERWISE NOTED
COMP	COMPOSITION	VCT	VINYL COMPOSITION TILE
CONC	CONCRETE	VERT	VERTICAL
CONST	CONSTRUCTION	VEST	VESTIBULE
CONT	CONTINUOUS	VIF	VERIFY IN FIELD
CORR	CORRIDOR	W	WEST
CT	CERAMIC TILE	w/	WITH
CUST	CUSTODIAN	W/O	WITHOUT
DBL	DOUBLE	WC	WATER CLOSET
DEMO	DEMOLITION	WD	WOOD
DEPT	DEPARTMENT	WH	WATER HEATER
DF	DRINKING FOUNTAIN		
DI	DRAIN OR DROP INLET		
DIA	DIAMETER		
DIAG	DIAGONAL		
DIM	DIMENSION		
DISP	DISPENSER		
DIV	DIVISION		
DN	DOWN		
DS	DOWNSPOUT		
DTL	DETAIL		
DW	DISHWASHER		
DWG	DRAWING		
(E)	EXISTING		
E	EAST		
EA	EACH		
EF	EXHAUST FAN		
EJ	EXPANSION JOINT		
EL	ELEVATION		
ELEC	ELECTRICAL		
ELEV	ELEVATOR		
ENCL	ENCLOSURE		
EQ	EQUAL		
EQUIP	EQUIPMENT		
EVA	EMERGENCY VEHICLE ACCESS		
EW	ELECTRICAL WATER COOLER		
EXP	EXPANSION		
EXT	EXTERIOR		
FA	FIRE ALARM		
FD	FLOOR DRAIN		
FE	FIRE EXTINGUISHER		
FEC	FIRE EXTINGUISHER CABINET		
FF	FINISH FLOOR		
FIN	FINISH		
FLR	FLOOR		
FO	FACE OF		
FOC	FACE OF CONCRETE		
FOF	FACE OF FINISH		
FOS	FACE OF STUD		
FRP	FIBERGLASS REINFORCED PANEL		
FT	FOOT OR FEET		
FTG	FOOTING		
GA	GAUGE		
GALV	GALVANIZED		
GB	GRAB BAR		
GSM	GALVANIZED SHEET METAL		
GYP	GYPSONUM		
HB	HOSE BIB		
HC	HOLLOW CORE		
HD	HEAD		
HDWR	HARDWARE		
HM	HOLLOW METAL		
HORIZ	HORIZONTAL		
HR	HOUR		
HT	HEIGHT		
INFO	INFORMATION		
INSUL	INSULATION		
INT	INTERIOR		
JAN	JANITOR		
JT	JOINT		
LAB	LABORATORY		
LAM	LAMINATE		
LAV	LAVATORY		
LBS	POUNDS		
LT	LIGHT		
MAX	MAXIMUM		
MB	MACHINE BOLT		
MDF	MEDIUM DENSITY FIRE BOARD		
MECH	MECHANICAL		
MFR	MANUFACTURER		
MH	MANHOLE		
MIN	MINIMUM		
MISC	MISCELLANEOUS		
MOD	MODULAR		
MTD	MOUNTED		
MTG	MOUNTING		
MTL	METAL		
MUL	MULLION		
(N)	NEW		
N/A	NOT APPLICABLE		
N	NORTH		
NIC	NOT IN CONTRACT		
NO or #	NUMBER		
NOM	NOMINAL		
NTS	NOT TO SCALE		
O	OVER		
OC	ON CENTER		
OFCI	OWNER FURNISHED CONTRACTOR INSTALLED		
OFDI	OWNER FURNISHED OWNER INSTALLED		
OPP	OPPOSITE		
PL	PLATE		
PLAM	PLASTIC LAMINATE		
PLAS	PLASTER		
PLYWD	PLYWOOD		
PR	PAIR		
PTD	PAPER TOWEL DISPENSER		
PVC	POLYVINYL CHLORIDE		
(R)	RELOCATE		
(RE)	RELOCATE EXISTING		
RB	RESILIENT OR RUBBER BASE		
RCP	REFLECTED CEILING PLAN		
RD	ROOF DRAIN		
REF	REFERENCE		
REFR	REFRIGERATOR		
REFN	REINFORCED		
REQ	REQUIRED		
RF	RESILIENT FLOORING		
RM	ROOM		
RO	ROUGH OPENING		
RWL	RAIN WATER LEADER		

SYMBOLS

(A)	GRID LINE
(1)	BUILDING ELEVATION
(1)	ELEVATION IDENTIFICATION
(1)	SHEET WHERE ELEVATION IS SHOWN
(1)	BUILDING OR WALL SECTION
(1)	SECTION IDENTIFICATION
(1)	SHEET WHERE SECTION IS SHOWN
(1)	DETAIL
(1)	DETAIL IDENTIFICATION
(1)	SHEET WHERE DETAIL IS SHOWN
(A)	INTERIOR ELEVATION(S)
(1)	DETAIL NO. OF ELEVATION
(1)	NO ARROWS MEAN ELEVATION NOT SHOWN
(1)	SHEET WHERE ELEVATION IS SHOWN
(1)	ELEVATION IDENTIFICATION
(1)	WORK POINT, CONTROL POINT OR DATUM POINT
(1)	REVISIONS
(1)	REVISION NUMBER, SEE REVISION SCHEDULE ON TITLE BLOCK
(1)	AREA OF REVISION
(1)	ROOM IDENTIFICATION
(1)	ROOM NAME
(1)	KAISER ROOM CODE NAME
(1)	ROOM NUMBER
(1)	CEILING HEIGHT (OTHER THAN 9'-0")
(1)	KEYNOTE TAG
(1)	REFER TO KEYNOTE LIST LOCATED ON PLAN SHEETS
(1)	AREA OF NO WORK
(1)	DOOR TAG (SEE DOOR SCHEDULE)
(1)	DOOR MARK
(1)	HARDWARE GROUP
(1)	DOOR MARK
(1)	(E) DOOR TO REMAIN
(1)	(E) DOOR TO BE REMOVED
(1)	(N) DOOR & DOOR FRAME
(1)	WALL TAG
(1)	WALL TYPE - REFER TO DRAWING SHEET A9.01
(1)	WINDOW TAG (SEE WINDOW SCHEDULE)
(1)	WINDOW MARK
(1)	CASEWORK TYPE: REFER TO W1 NORTH AMERICAN ARCHITECTURAL WOODWORK & OWNER CASEWORK STANDARDS
(1)	CASEWORK DIMENSIONS
(1)	CUSTOMIZATIONS & SPECIALTY HARDWARE

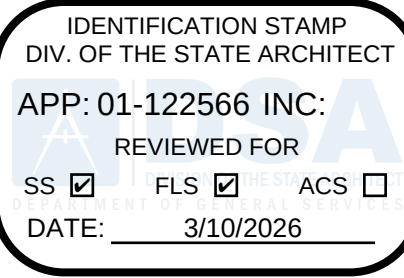

Revisions	Delta	Date	Revisions	By
-----------	-------	------	-----------	----

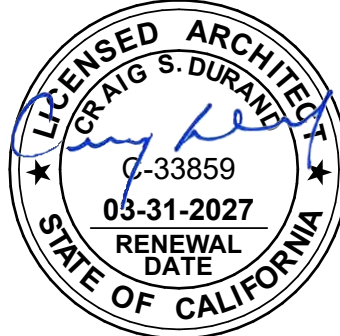

HY Architects Project number: Project Number

Facility
SKYLINE ELEMENTARY SCHOOL
55 CHRISTEN AVE, DALY CITY, CA 94015


Project
HVAC REPLACEMENT

Sheet Title
SYMBOLS, LEGENDS AND ABBREVIATIONS

Client Project Number: 0000.0

Scale: 12" = 1'-0"
Drawn By: Author
Checked By: Checker
Issue Date: Issue Date
Revit Version: 2023
Sheet
A0.02
Sheet 2 of 200

C:\Users\alio\Documents\6241 SSF USD Skyline ES HVAC_R22_Central_Airlock\ZLN.rvt 2/18/2023 2:47:10 PM

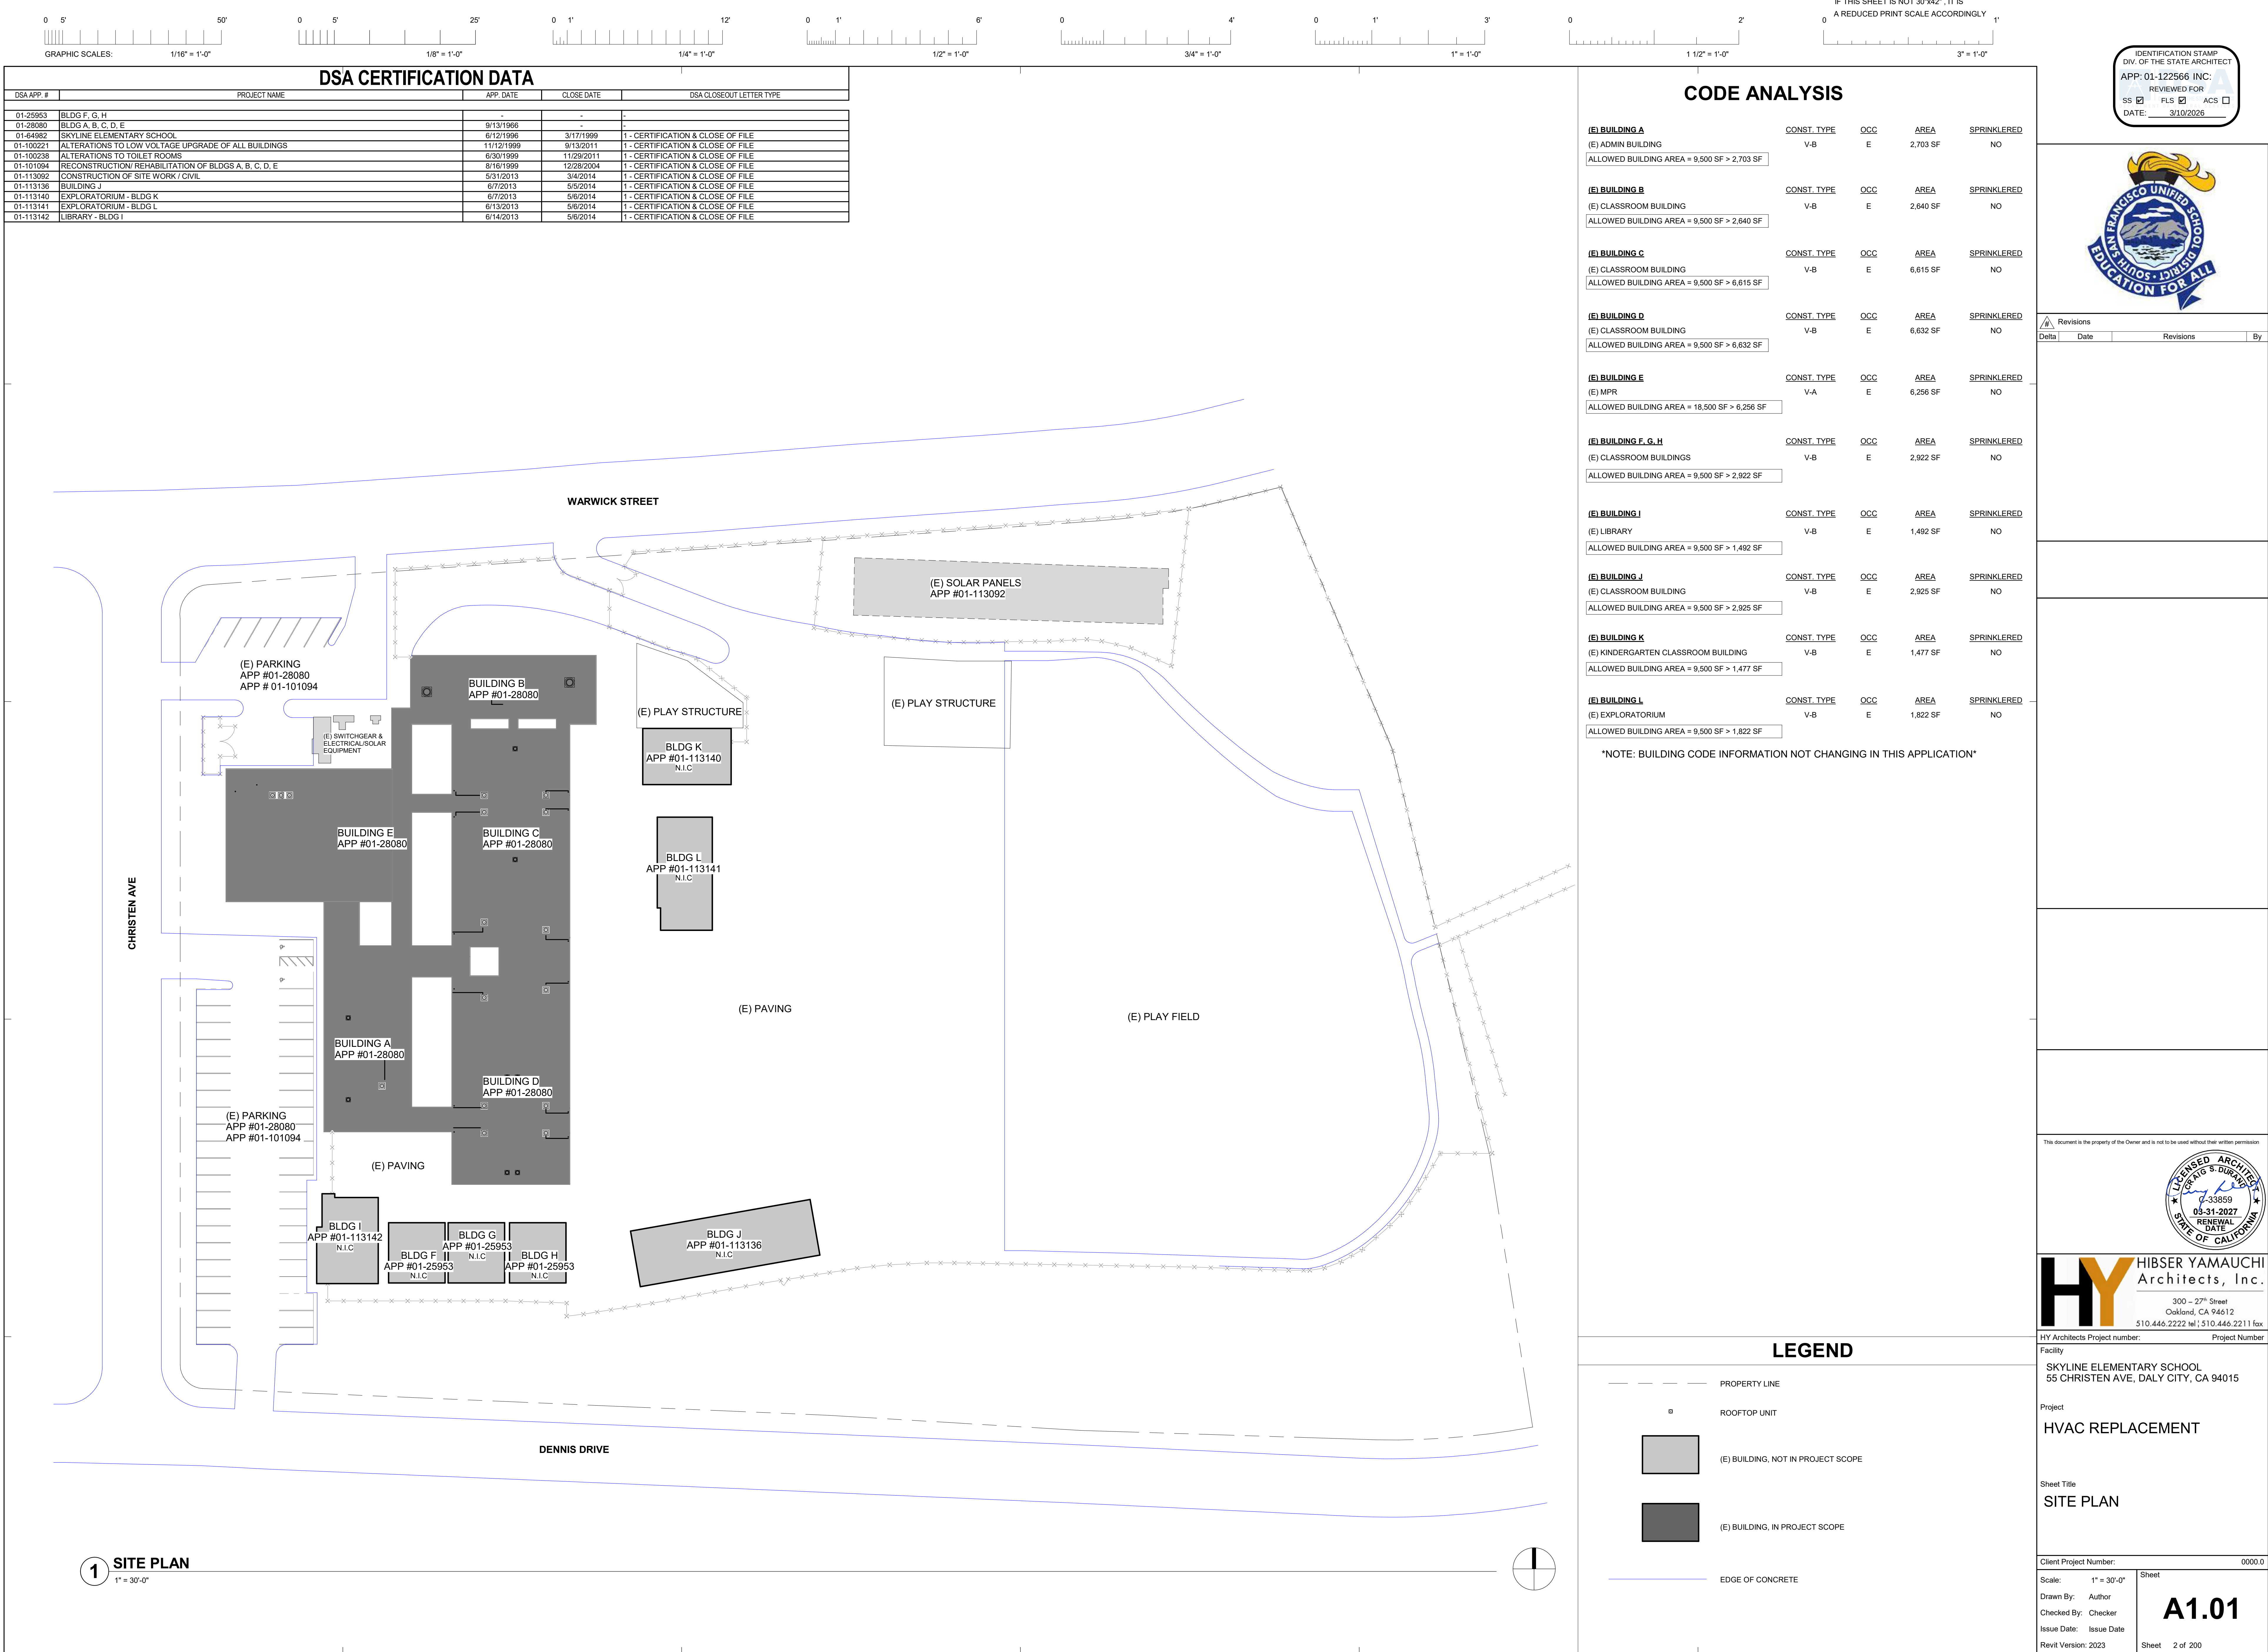



IF THIS SHEET IS NOT 30"x42", IT IS
A REDUCED PRINT SCALE ACCORDINGLY


IDENTIFICATION STAMP
DIV. OF THE STATE ARCHITECT

APP: 01-122566 INC:
REVIEWED FOR
SS ☒ FLS ☒ ACS ☐
DATE: 3/10/2026



Revisions			
Delta	Date	Revisions	By

KEY PLAN

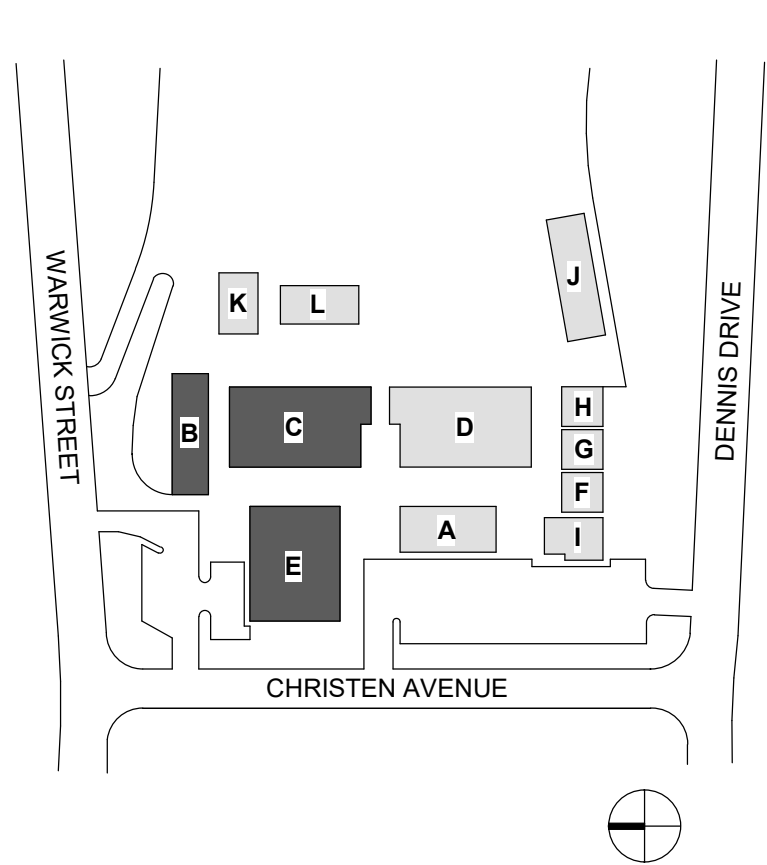

DEMO NOTES

D2.01	DEMO (E) DOOR AND FRAME, SALVAGE (E) DEADBOLT AND STRIKE FOR REINSTALLATION
D2.05	DEMO (E) LOUVERS AT EXTERIOR WALL
D2.08	DEMO (E) FURNACE, SMD
D2.12	DEMO WALL ABOVE (E) OPENING AND RELOCATE (E) HEADER +18" TO ACCOMMODATE (N) DOOR


KEYNOTES

DEMO LEGEND

Room Name	ROOM TAG
#	
	(E) FURNACE TO BE DEMOLISHED, SMD
	(E) DOOR TO REMAIN
	(E) DOOR TO BE DEMOLISHED
	(E) LOUVER TO BE DEMOLISHED


2 DEMO FLOOR PLAN - BLDG B, C, & E

1/8" = 1'-0"

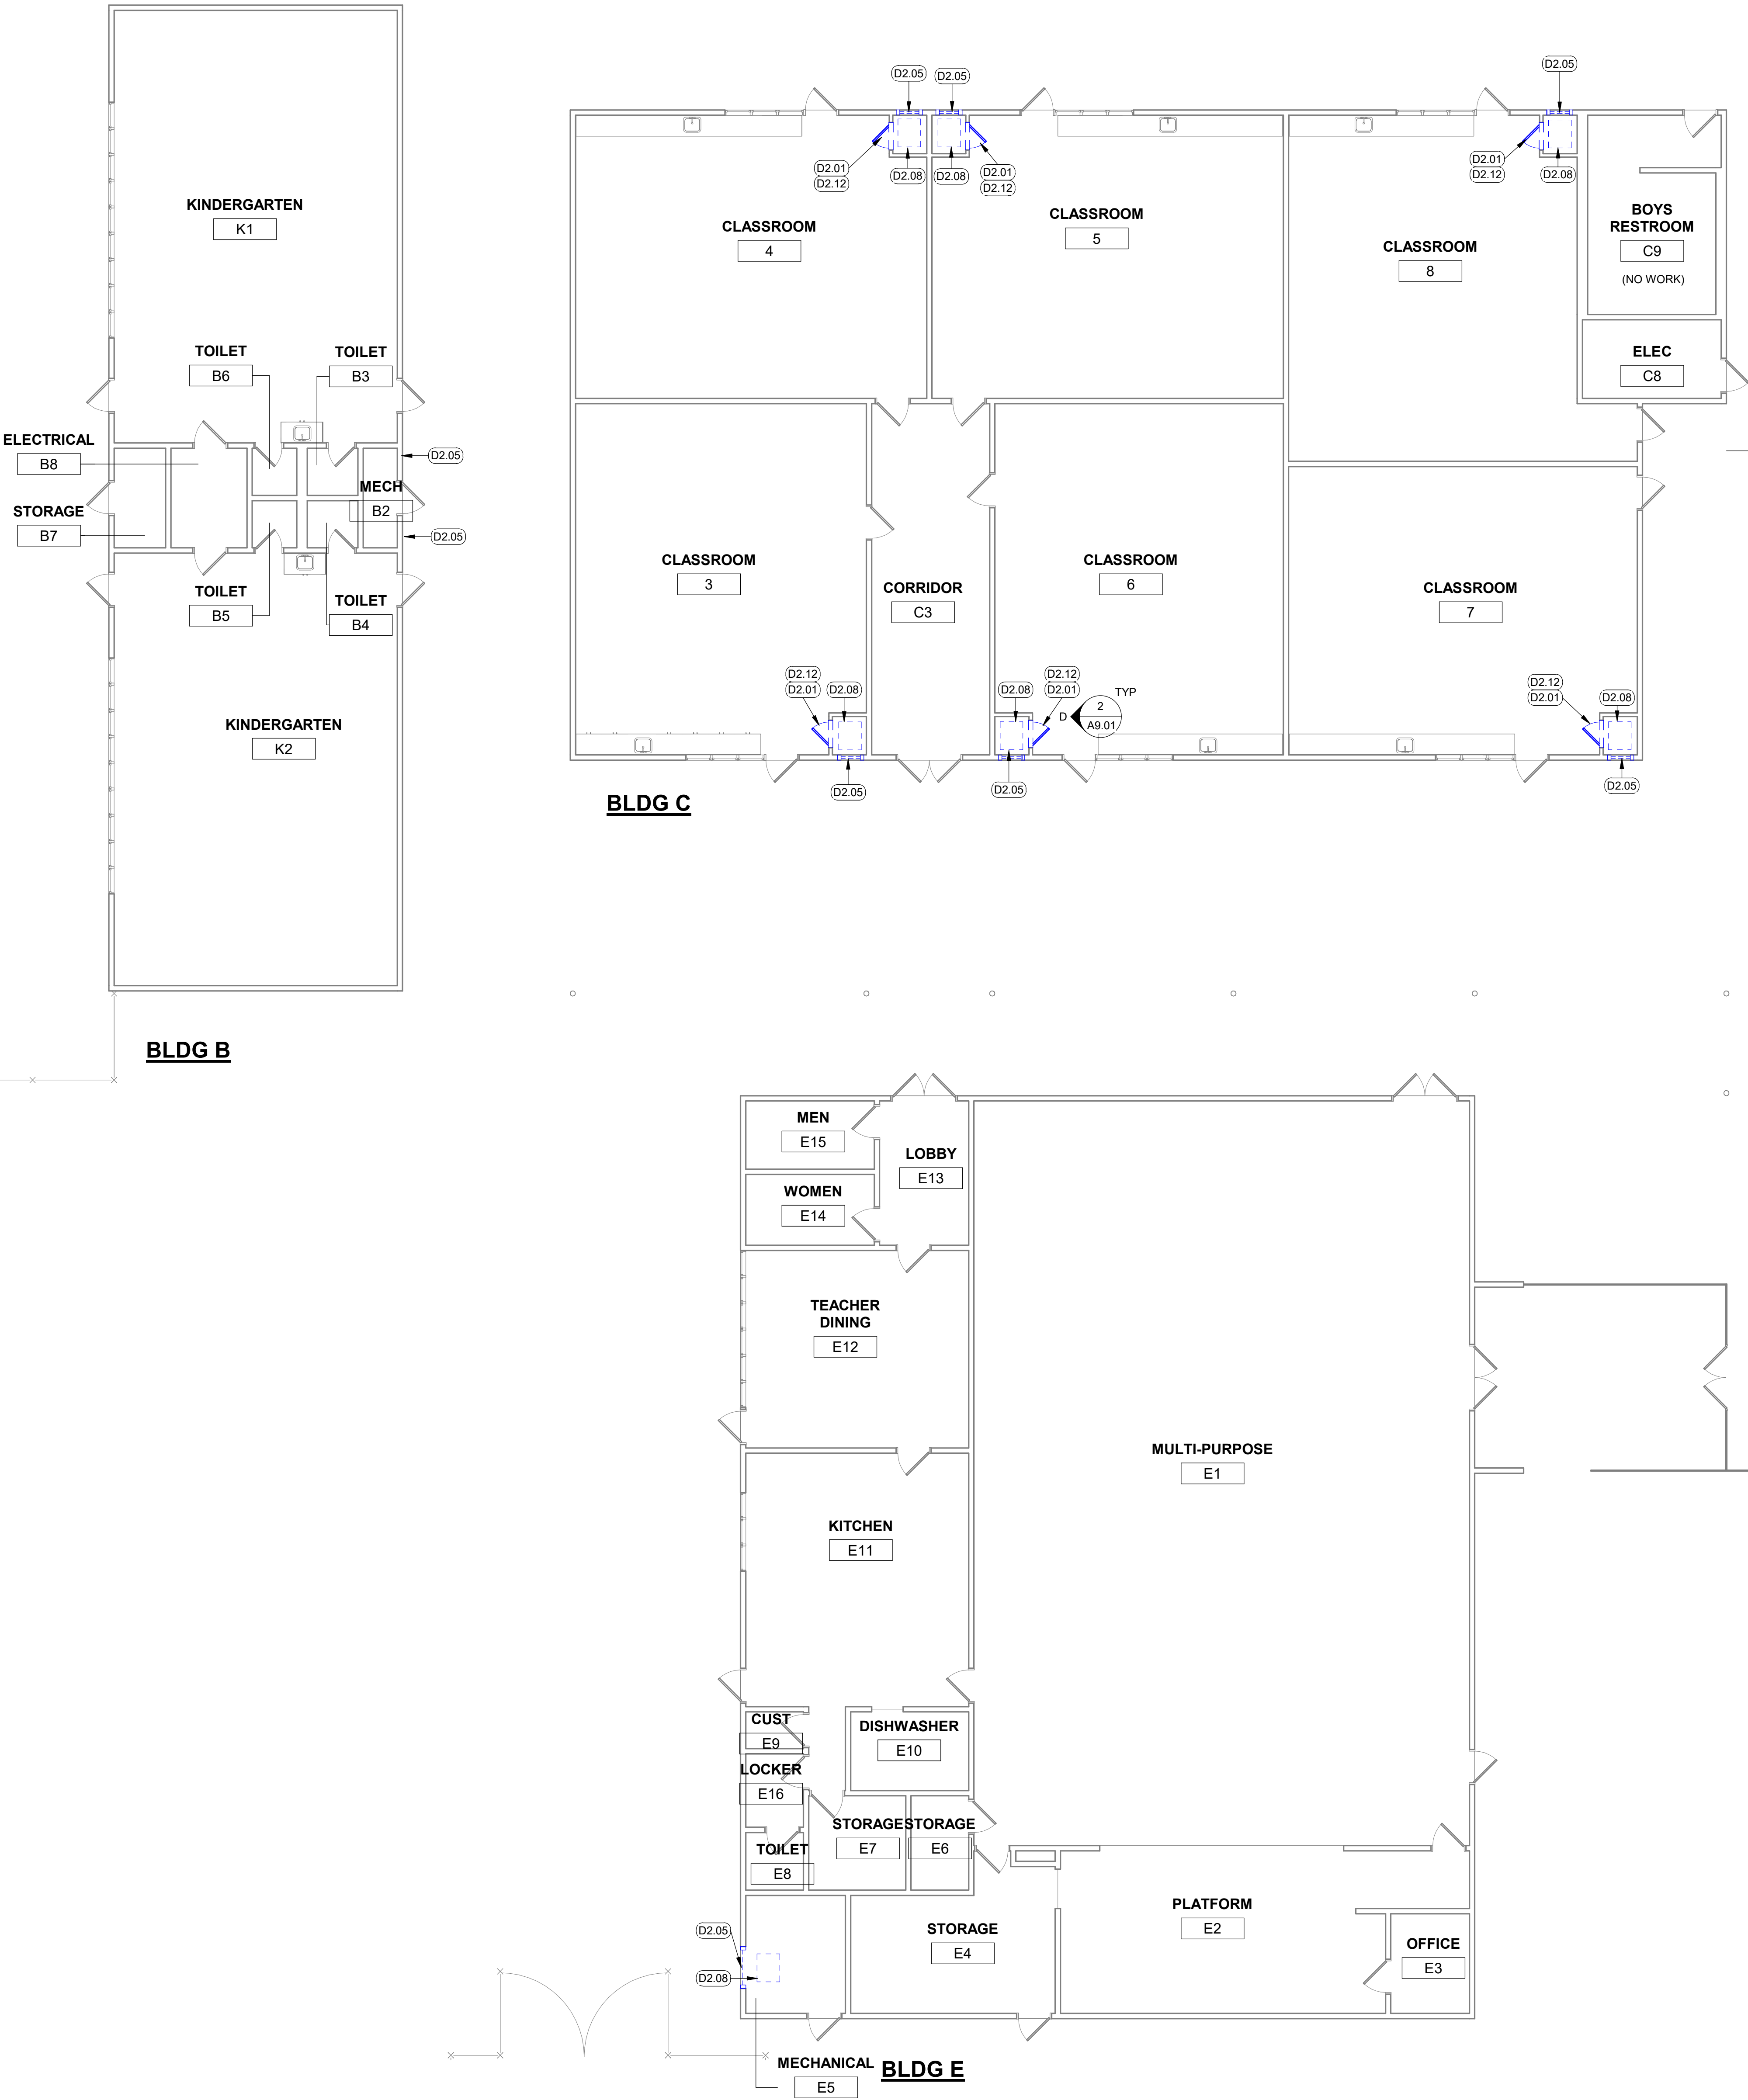


MATCHLINE SEE A2.02

MATCHLINE SEE A2.02

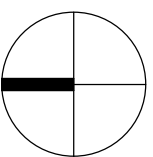

This document is the property of the Owner and is not to be used without their written permission

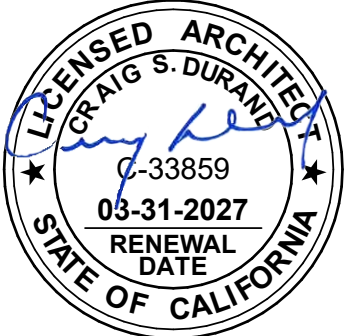

HY HIBSER YAMAUCHI
Architects, Inc.

300 - 27th Street
Oakland, CA 94612
510.446.2222 tel | 510.446.2211 fax

HY Architects Project number: Project Number

Facility
SKYLINE ELEMENTARY SCHOOL
55 CHRISTEN AVE, DALY CITY, CA 94015

Project
HVAC REPLACEMENT

Sheet Title
DEMOLITION PLAN - BUILDING
B, C, & E

Client Project Number: 0000.0

Scale: As indicated

Drawn By: Author

Checked By: Checker

Issue Date: Issue Date

Revit Version: 2023

A2.01

Sheet 2 of 200



IF THIS SHEET IS NOT 30"x42", IT IS
A REDUCED PRINT SCALE ACCORDINGLY

IDENTIFICATION STAMP
DIV. OF THE STATE ARCHITECT

APP: 01-122566 INC:

REVIEWED FOR


SS ☒ FLS ☒ ACS ☐

DATE: 3/10/2026



Revisions			
Delta	Date	Revisions	By

KEY PLAN

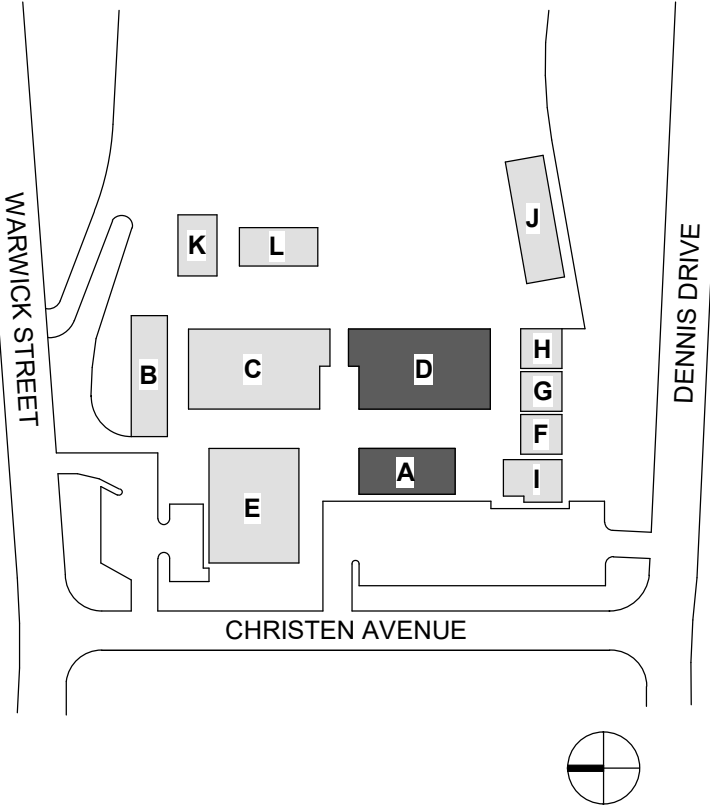


DEMO NOTES

D2.01	DEMO (E) DOOR AND FRAME, SALVAGE (E) DEADBOLT AND STRIKE FOR REINSTALLATION.
D2.05	DEMO (E) LOUVERS AT EXTERIOR WALL
D2.06	DEMO (E) LOUVER IN (E) DOOR, (E) DOOR TO REMAIN
D2.08	DEMO (E) FURNACE, SMD
D2.12	DEMO WALL ABOVE (E) OPENING AND RELOCATE (E) HEADER +18" TO ACCOMMODATE (N) DOOR

KEYNOTES

This document is the property of the Owner and is not to be used without their written permission

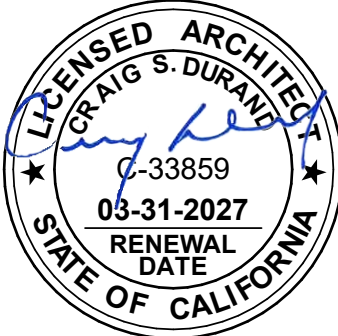

HY HIBSER YAMAUCHI Architects, Inc.

300 - 27th Street
Oakland, CA 94612
510.446.2222 tel | 510.446.2211 fax

HY Architects Project number: Project Number

Facility
SKYLINE ELEMENTARY SCHOOL
55 CHRISTEN AVE, DALY CITY, CA 94015

Project
HVAC REPLACEMENT

Sheet Title
DEMOLITION PLAN - BUILDING A & D

Client Project Number: 0000.0

Scale: As indicated

Drawn By: Author

Checked By: Checker



Issue Date: Issue Date

Revit Version: 2023

A2.02

Sheet 2 of 200

1 DEMO FLOOR PLAN - BUILDING A & D
1/8" = 1'-0"

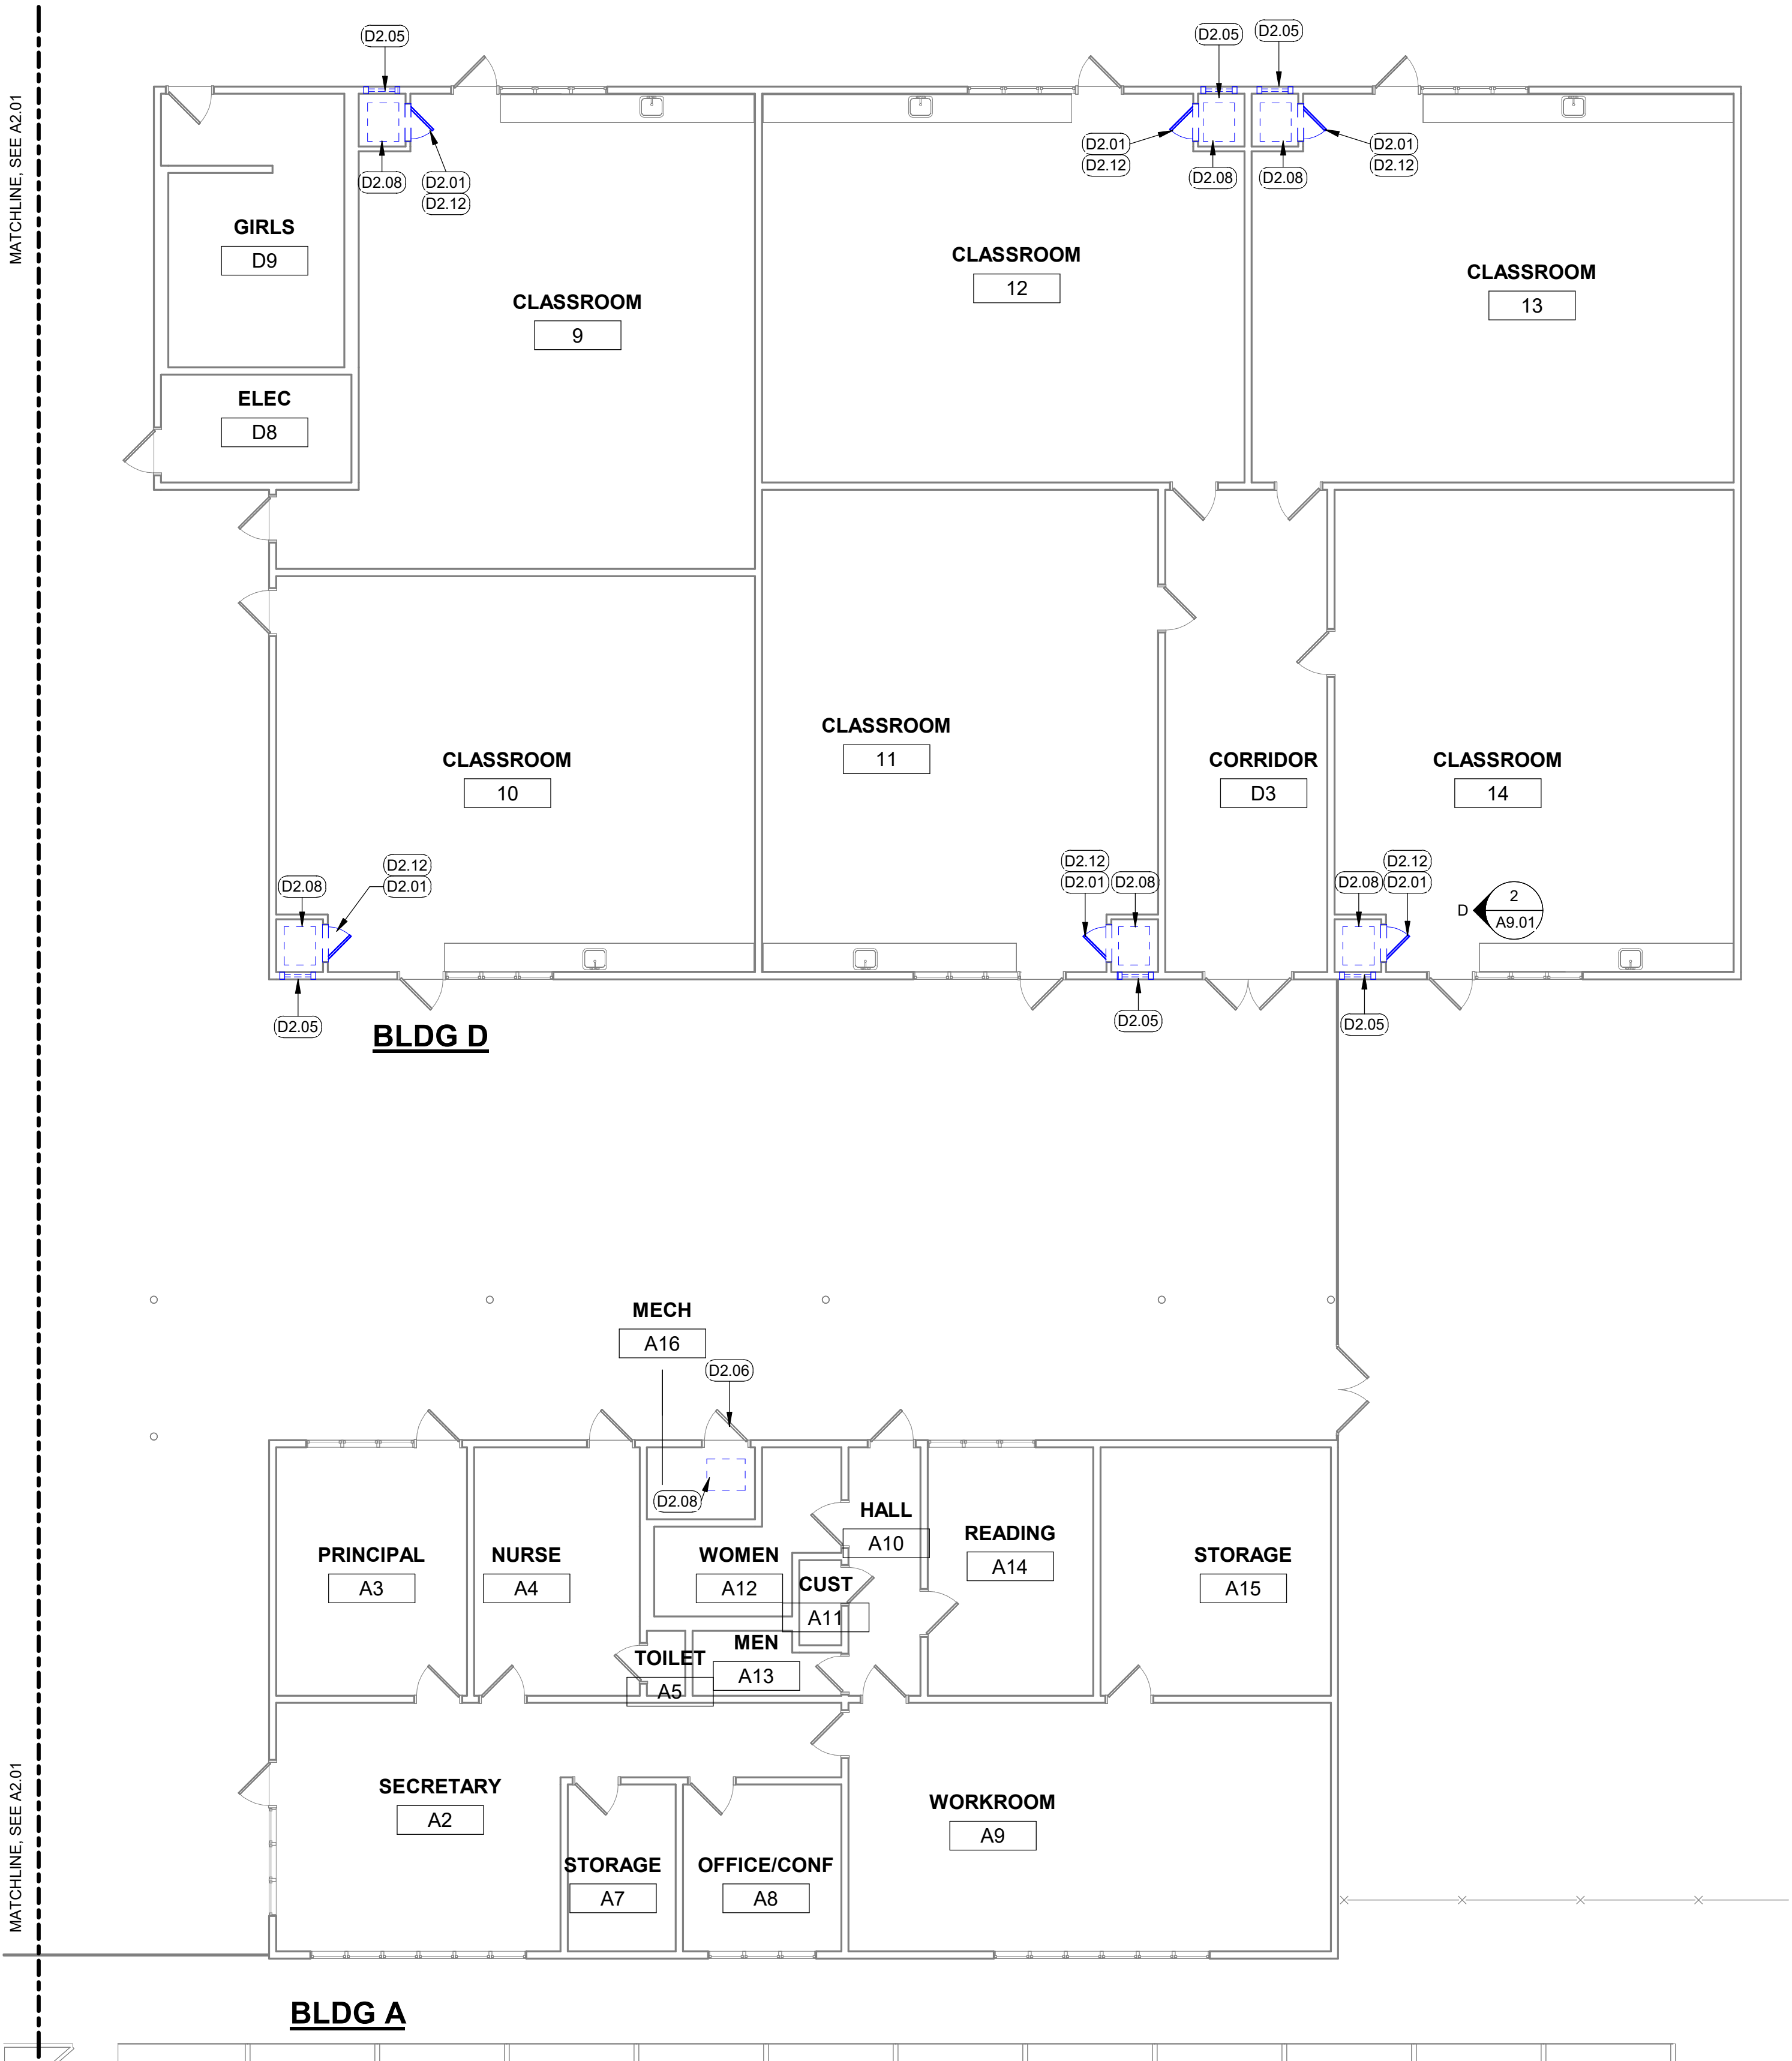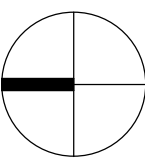




IDENTIFICATION STAMP
DIV. OF THE STATE ARCHITECT

APP: 01-122566 INC:
REVIEWED FOR
SS ☒ FLS ☒ ACS ☐
DATE: 3/10/2026



Revisions			
Delta	Date	Revisions	By

KEY PLAN

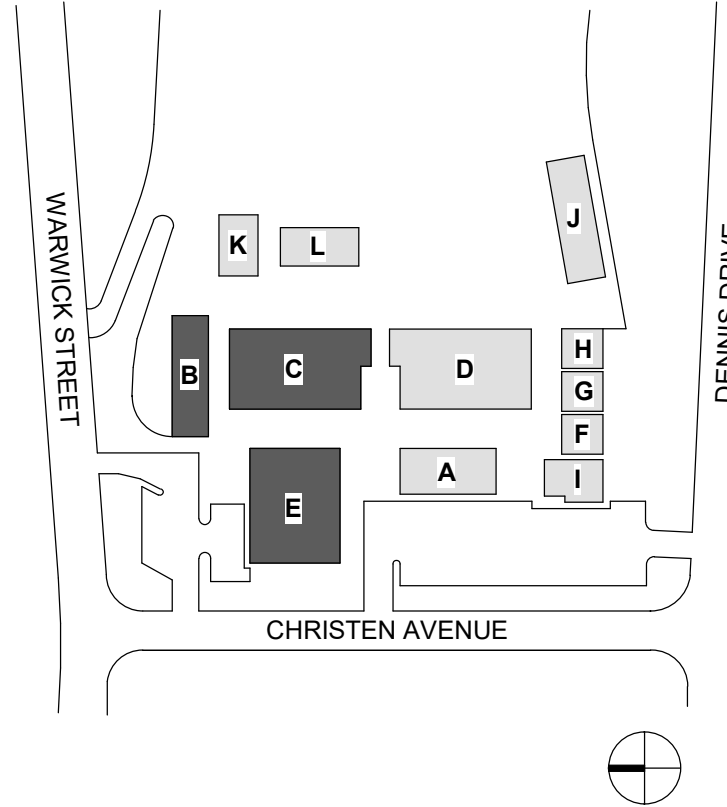

GENERAL NOTES


1. PRIOR TO START OF CONSTRUCTION CONTRACTOR TO FIELD VERIFY (E) CONDITIONS & NOTIFY ARCHITECT OF ANY DISCREPANCIES FROM THE PLANS.
2. PRIOR TO START OF CONSTRUCTION CONTRACTOR TO REMOVE & PROTECT ALL (E) EQUIPMENT & FURNITURE. RELEASE BACK TO THE FACILITY FOR FUTURE RE-USE UON OR UNLESS DIRECTED BY THE OWNER.
3. ALL DIMENSIONS SHALL BE FROM FACE OF STUD. UON. DIMENSIONS NOTED AS "CLR" REFER TO CLEAR DIMENSION FROM FACE OF FINISH.
4. WHEREVER THE TERM "ALIGN" IS SHOWN, CONTRACTOR TO ALIGN THE FACES OF WALL FINISH(ES).
5. PROTECT & MAINTAIN ALL (E) PARTITION RATINGS, UON.
6. PRESERVE & PROTECT (E) FINISHES THAT ARE TO REMAIN. WHERE DAMAGE OCCURS DURING CONSTRUCTION PATCH & REPAIR ALL WALLS, CEILING, AND FLOOR SURFACES TO MATCH (E), UON. IF FINISHES ARE DAMAGED BEYOND REPAIR & AN EXACT MATCH CANNOT BE PROCURED NOTIFY THE ARCHITECT IMMEDIATELY FOR DIRECTION ON REPLACEMENT FINISH SPECIFICATION. WALLS SHALL BE PAINTED TO THE NEAREST CORNER/ INTERSECTION & ALL OTHER FINISHES TO BE REPLACED AT THE NEAREST CORNER/ INTERSECTION FOR A SEAMLESS AESTHETIC.
7. REFER TO STRUCTURAL, MECHANICAL, AND ELECTRICAL SERIES SHEETS FOR ADDITIONAL INFORMATION. COORDINATE LOCATIONS OF WALL MOUNTED ACCESSORIES, EQUIPMENT, FURNITURE, SIGNAGE & THEIR ASSOCIATED BACKING WITH POWER/DATA, THERMOSTAT, LIGHT SWITCH & MISC. PANEL LOCATIONS PRIOR TO INSTALLATION.

KEYNOTES


02.03	(E) HSS STEEL COLUMN
08.01	DOOR, SEE SCHEDULE, TYP.
08.02	LOUVER, SEE SCHEDULE
23.03	FURNACE, SMD

LEGEND


Room Name	ROOM TAG
##	
	FURNACE, SMD
	(E) DOOR TO REMAIN
	DOOR, SEE SCHEDULE
	LOUVER, SEE SCHEDULE
	LOUVER TAG, SEE SCHEDULE
	DOOR NUMBER
	DOOR TAG, SEE SCHEDULE
	HARDWARE SET

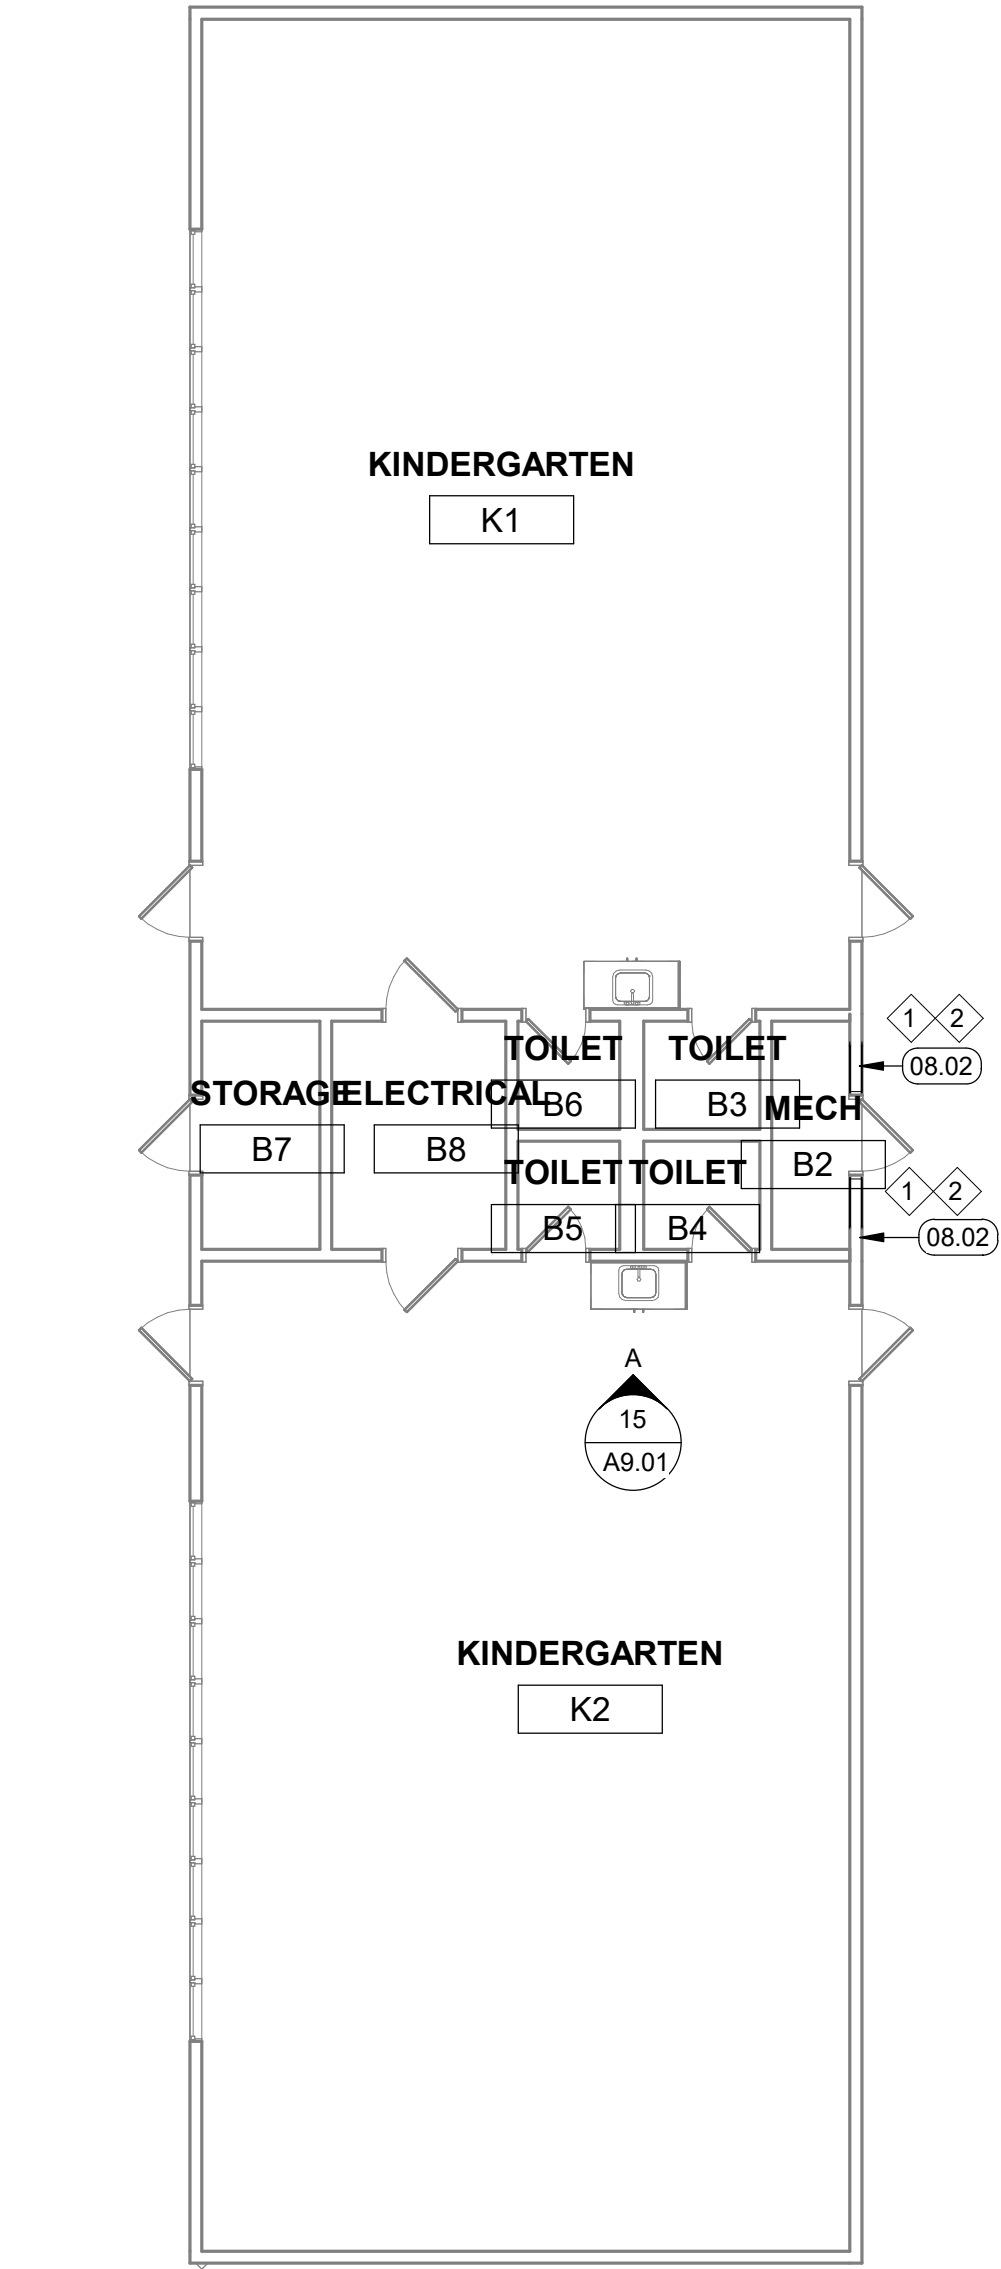

BLDG B

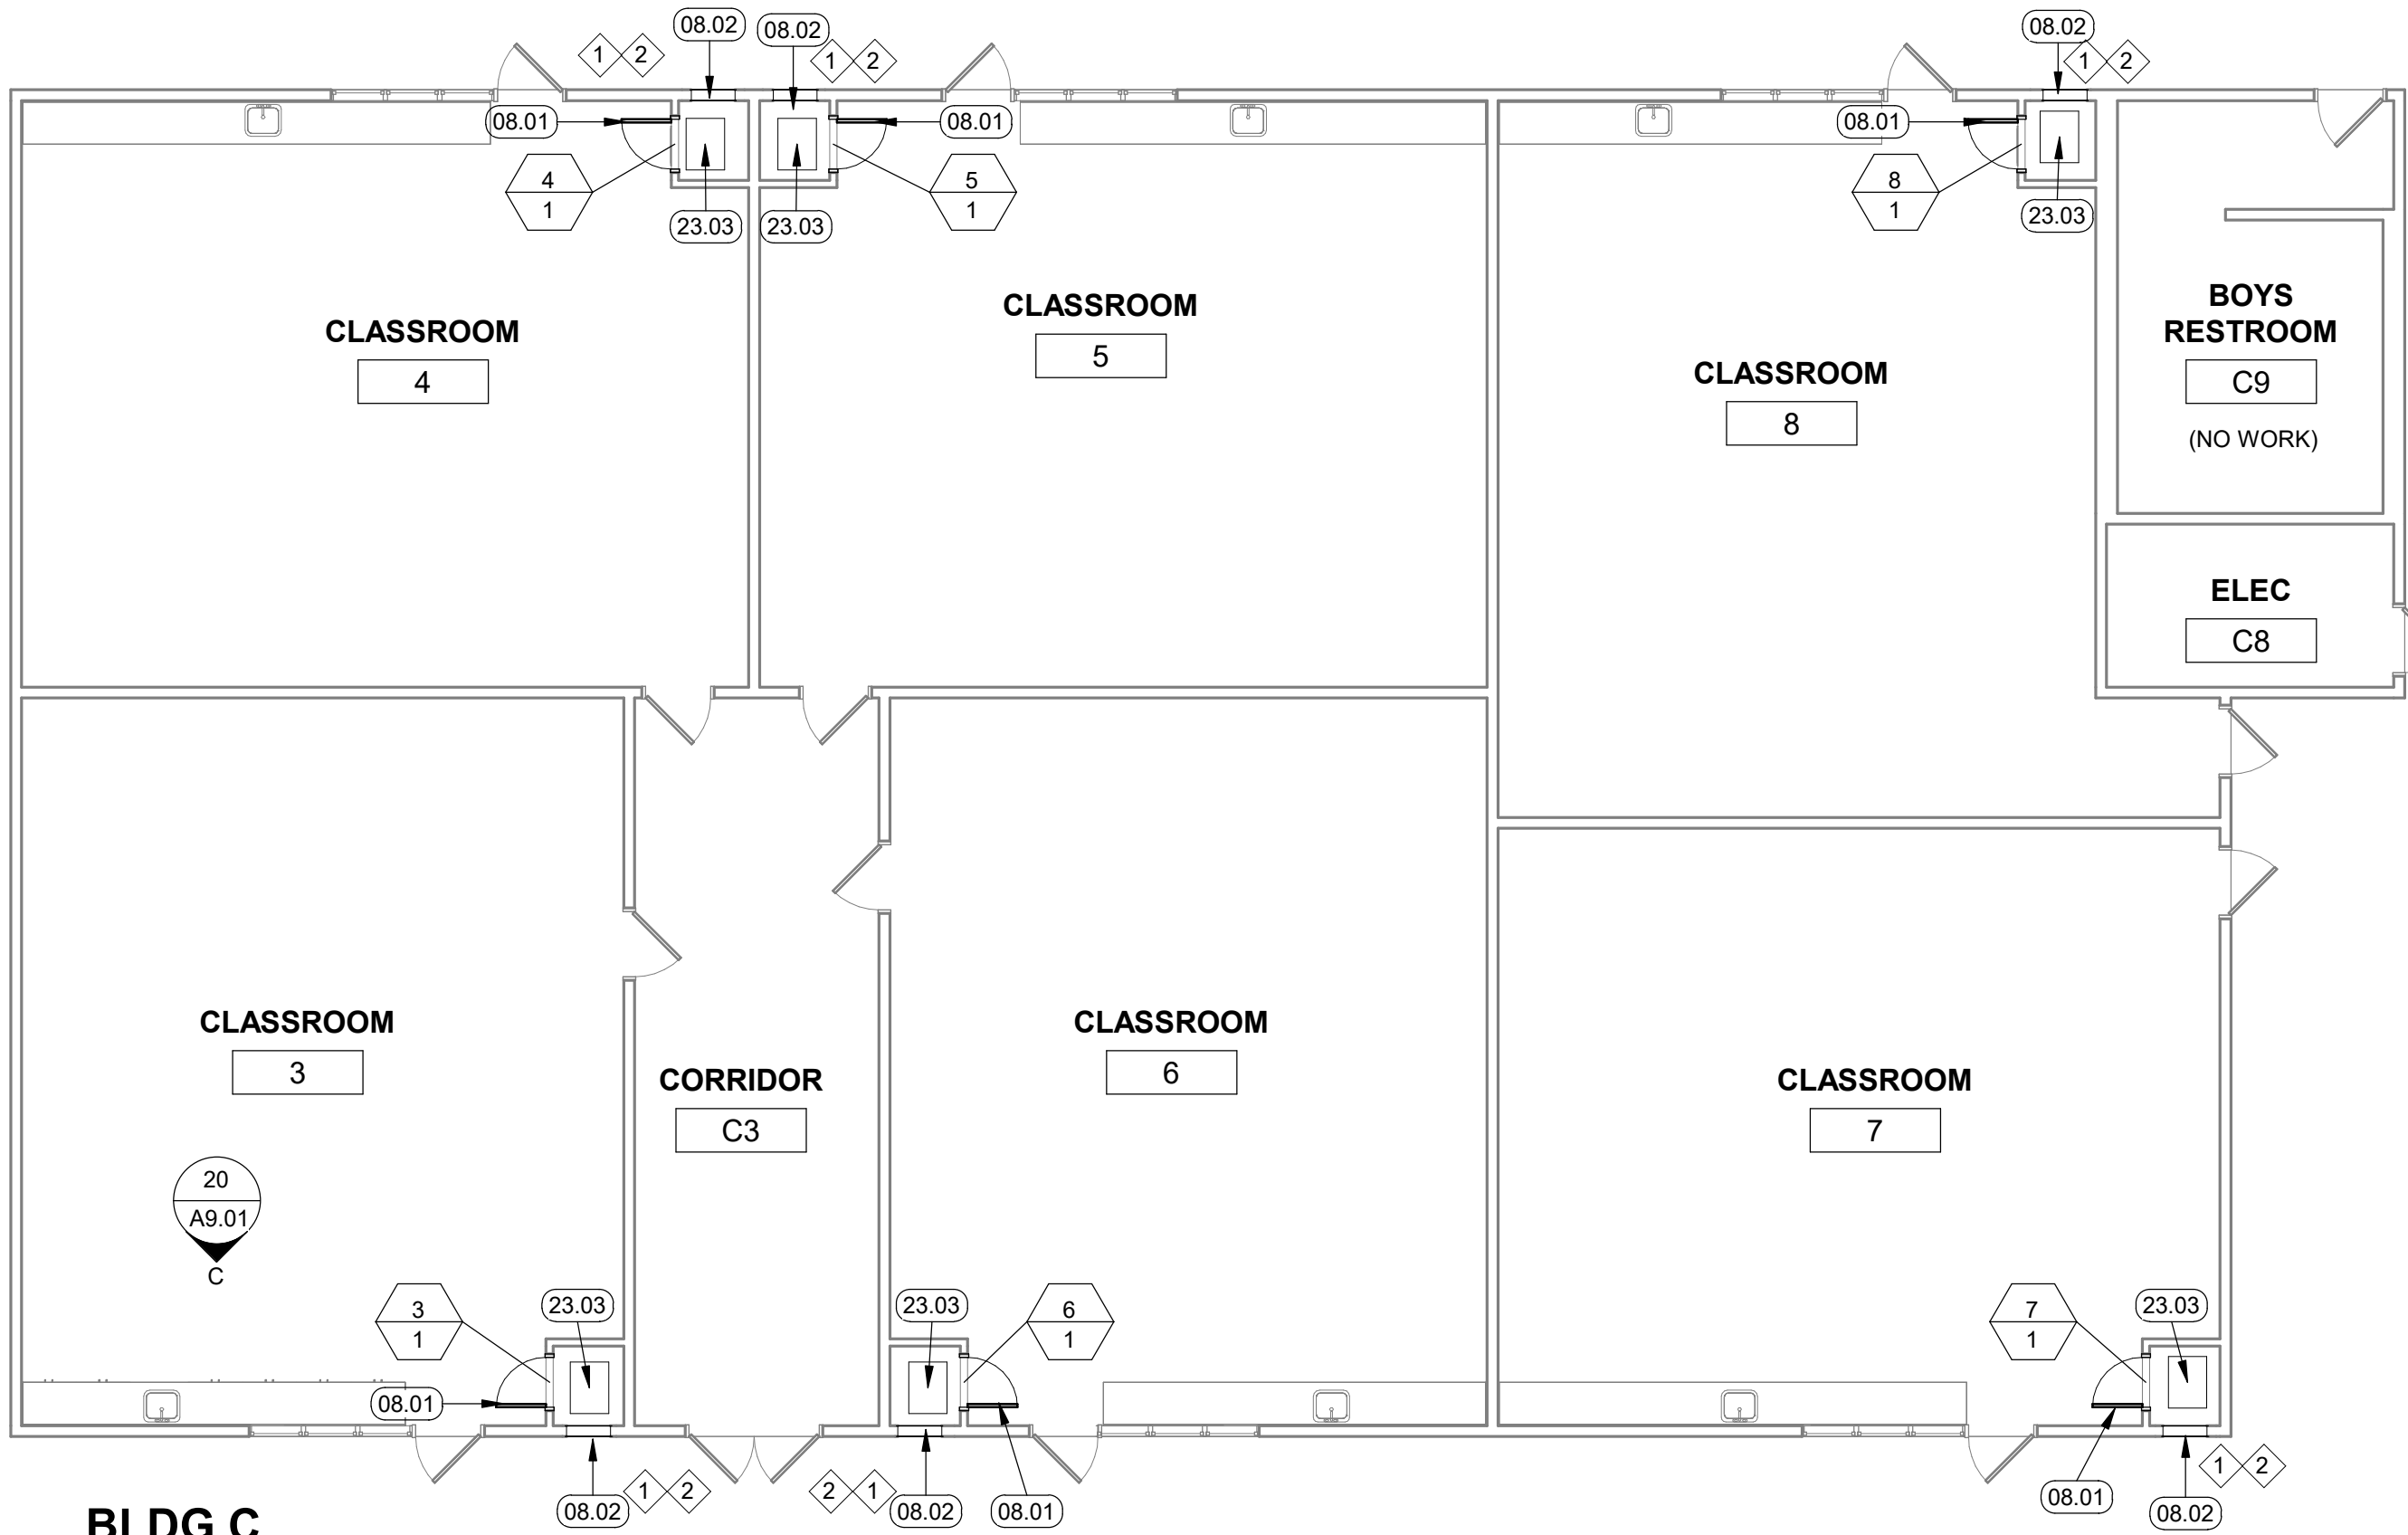


BLDG C

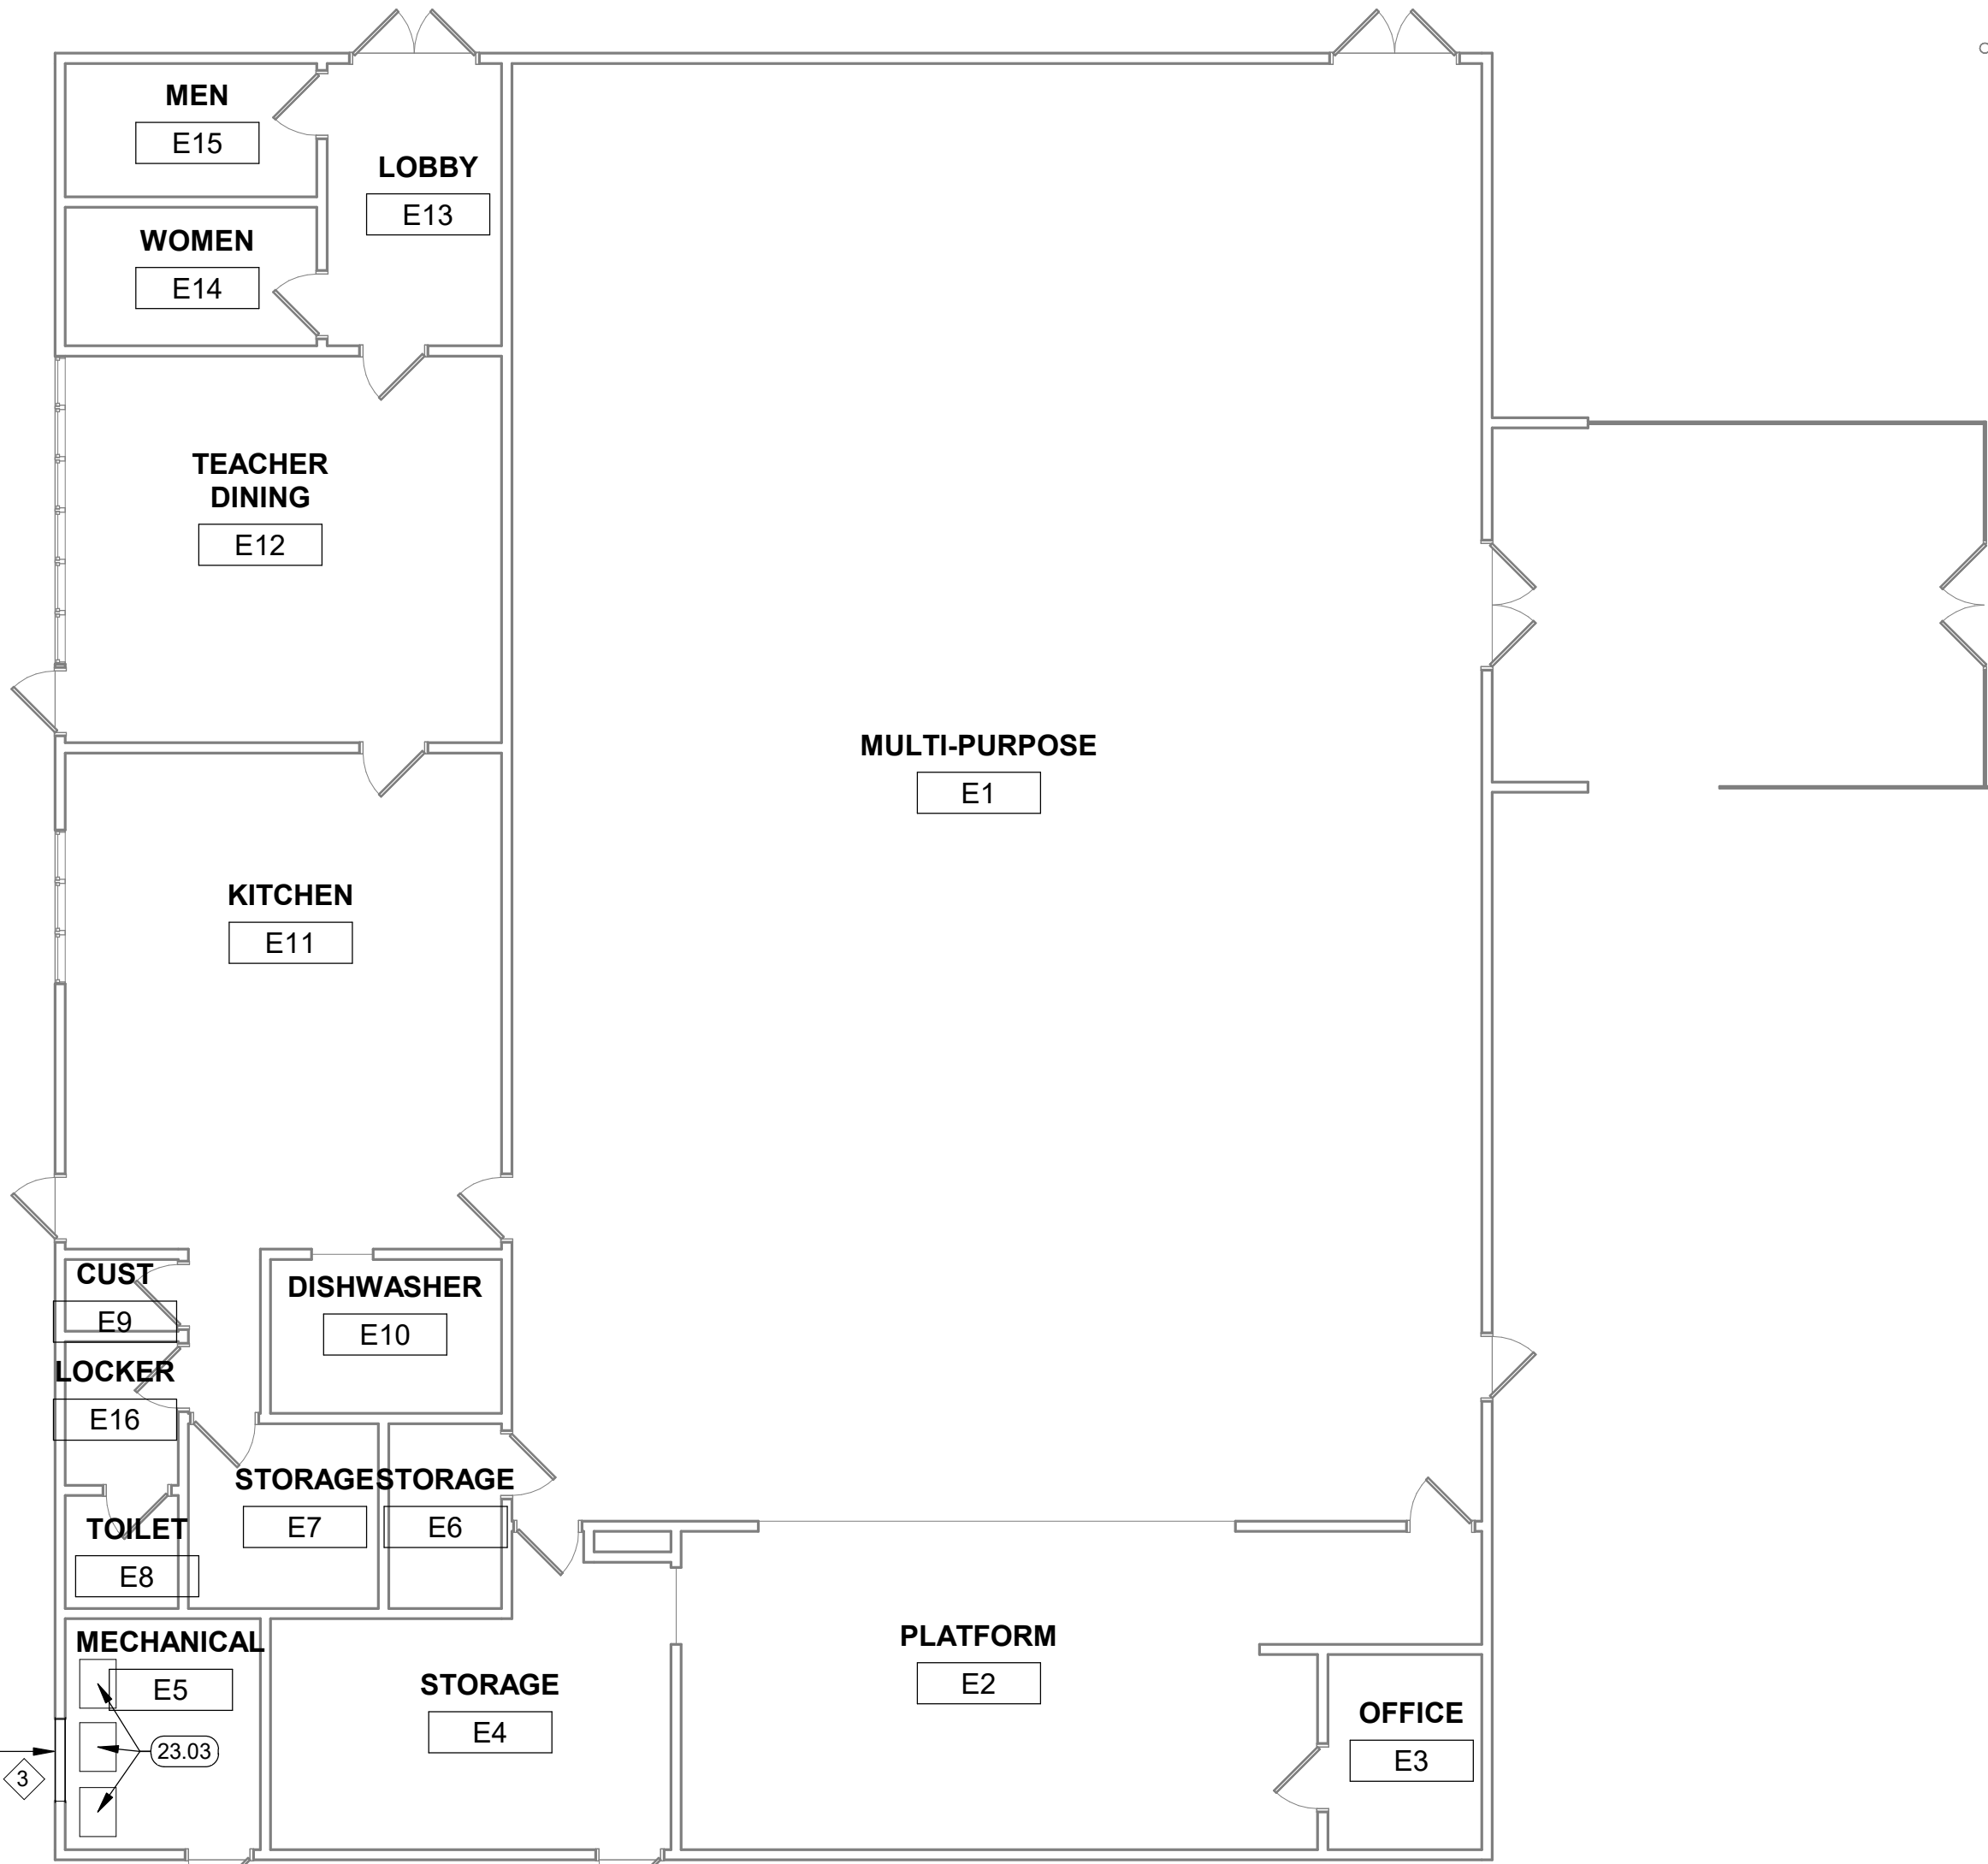

BLDG E

3 FIRST FLOOR PLAN - BUILDING B, C, & E
1/8" = 1'-0"

This document is the property of the Owner and is not to be used without their written permission.

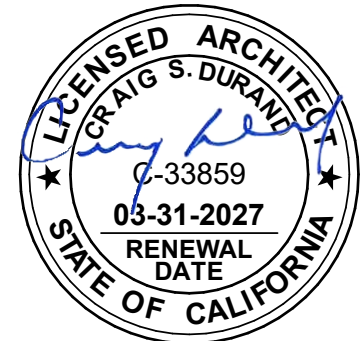

HY HIBSER YAMAUCHI
Architects, Inc.

300 - 27th Street
Oakland, CA 94612
510.446.2222 tel; 510.446.2211 fax

HY Architects Project number: Project Number

Facility
SKYLINE ELEMENTARY SCHOOL
55 CHRISTEN AVE, DALY CITY, CA 94015

Project
HVAC REPLACEMENT

Sheet Title
FLOOR PLAN - BUILDING B, C, & E


Client Project Number: 0000.0

Scale: As indicated
Drawn By: Author
Checked By: Checker
Issue Date: Issue Date
Revit Version: 2023

Sheet
2 of 200

A2.03

C:\Users\alicia\Documents\6241 SFUSD Skyline ES HVAC_R05_Central_Auditorium.dwg 2/18/2025 2:47:15 PM

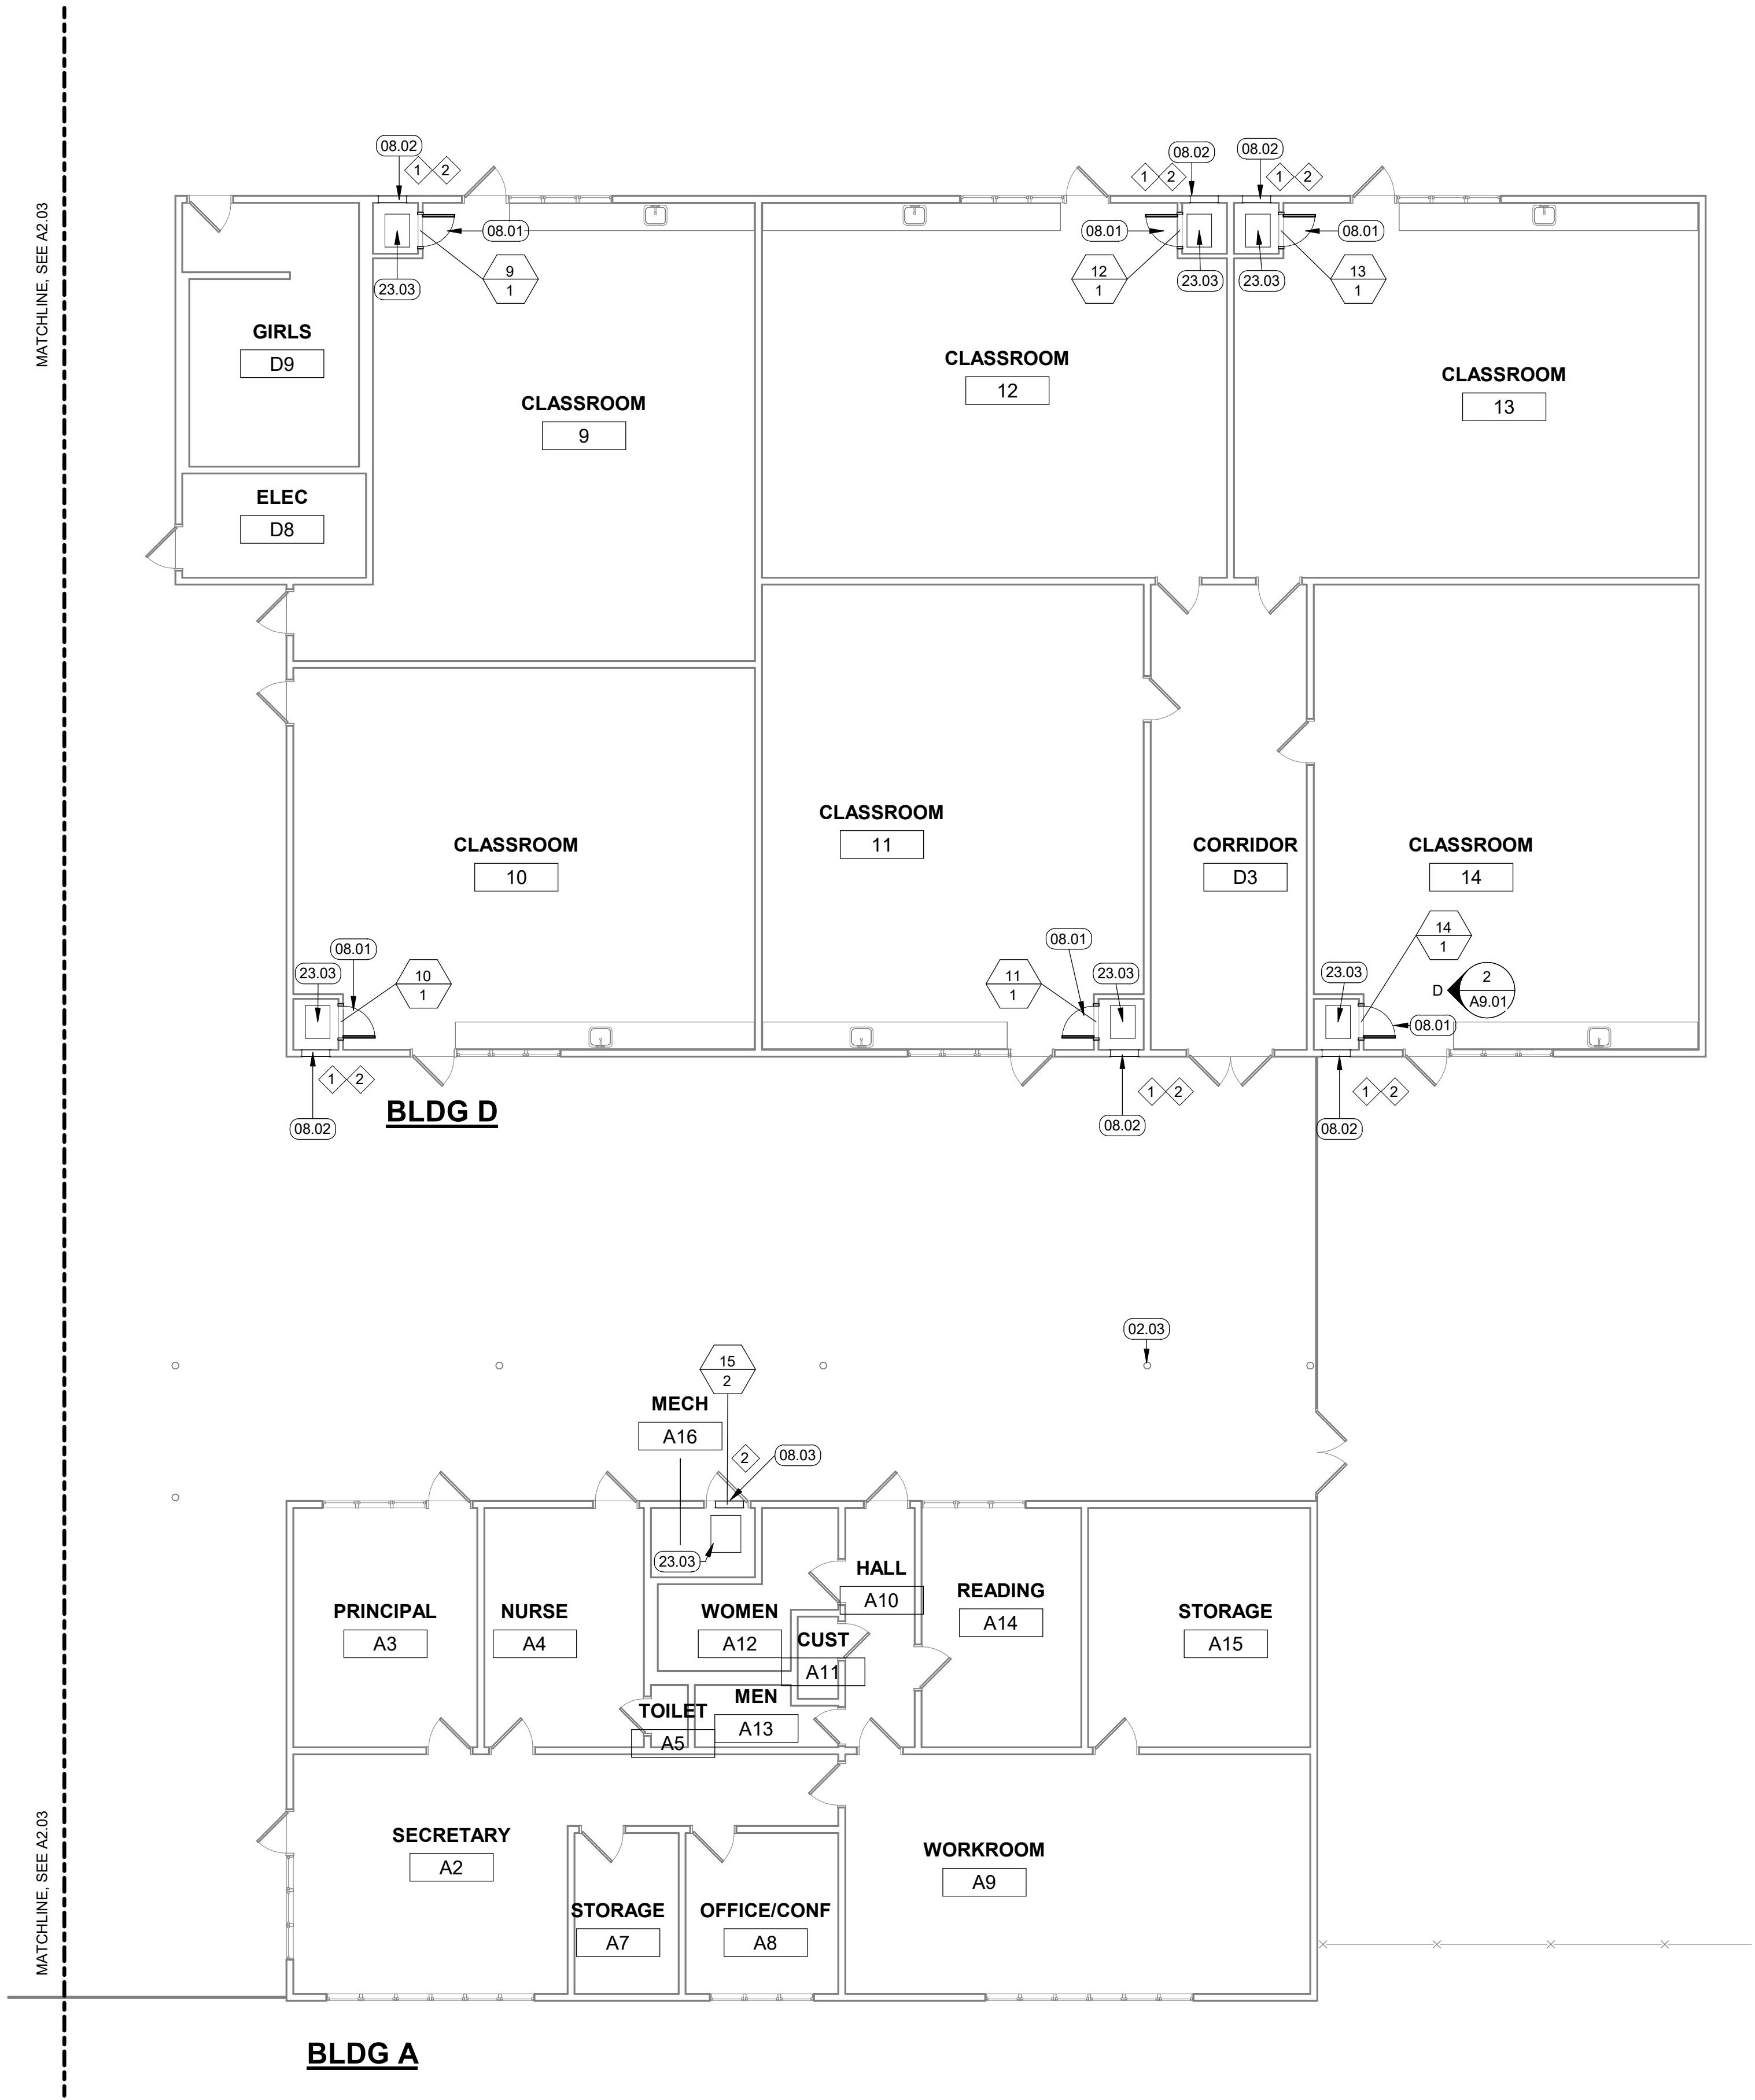

1 FIRST FLOOR PLAN - BUILDING A & D
1/8" = 1'-0"

GENERAL NOTES


1. PRIOR TO START OF CONSTRUCTION CONTRACTOR TO FIELD VERIFY (E) CONDITIONS & NOTIFY ARCHITECT OF ANY DISCREPANCIES FROM THE PLANS.
2. PRIOR TO START OF CONSTRUCTION CONTRACTOR TO REMOVE & PROTECT ALL (E) EQUIPMENT & FURNITURE. RELEASE BACK TO THE FACILITY FOR FUTURE RE-USE UON OR UNLESS DIRECTED BY THE OWNER.
3. ALL DIMENSIONS SHALL BE FROM FACE OF STUD, UON. DIMENSIONS NOTED AS "CLR" REFER TO CLEAR DIMENSION FROM FACE OF FINISH.
4. WHEREVER THE TERM "ALIGN" IS SHOWN, CONTRACTOR TO ALIGN THE FACES OF WALL FINISH(ES).
5. PROTECT & MAINTAIN ALL (E) PARTITION RATINGS, UON.
6. PRESERVE & PROTECT (E) FINISHES THAT ARE TO REMAIN. WHERE DAMAGE OCCURS DURING CONSTRUCTION PATCH & REPAIR ALL WALLS, CEILING, AND FLOOR SURFACES TO MATCH (E), UON. IF FINISHES ARE DAMAGED BEYOND REPAIR & AN EXACT MATCH CANNOT BE PROCURED NOTIFY THE ARCHITECT IMMEDIATELY FOR DIRECTION ON REPLACEMENT FINISH SPECIFICATION. WALLS SHALL BE PAINTED TO THE NEAREST CORNER/ INTERSECTION & ALL OTHER FINISHES TO BE REPLACED AT THE NEAREST CORNER/ INTERSECTION FOR A SEAMLESS AESTHETIC.
7. REFER TO STRUCTURAL, MECHANICAL, AND ELECTRICAL SERIES SHEETS FOR ADDITIONAL INFORMATION. COORDINATE LOCATIONS OF WALL MOUNTED ACCESSORIES, EQUIPMENT, FURNITURE, SIGNAGE & THEIR ASSOCIATED BACKING WITH POWER/ DATA, THERMOSTAT, LIGHT SWITCH & MISC. PANEL LOCATIONS PRIOR TO INSTALLATION.

KEYNOTES

02.03	(E) HSS STEEL COLUMN
08.01	DOOR, SEE SCHEDULE, TYP.
08.02	LOUVER, SEE SCHEDULE
08.03	LOUVER IN DOOR, SEE SCHEDULE
23.03	FURNACE, SMD


LEGEND

Room Name	ROOM TAG
##	
	FURNACE, SMD
	(E) DOOR TO REMAIN
	DOOR, SEE SCHEDULE
	LOUVER, SEE SCHEDULE
	LOUVER TAG, SEE SCHEDULE
	DOOR NUMBER
	DOOR TAG, SEE SCHEDULE
	HARDWARE SET

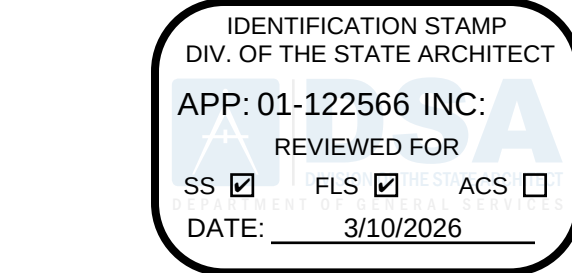


Revisions	Delta	Date	Revisions	By

KEY PLAN

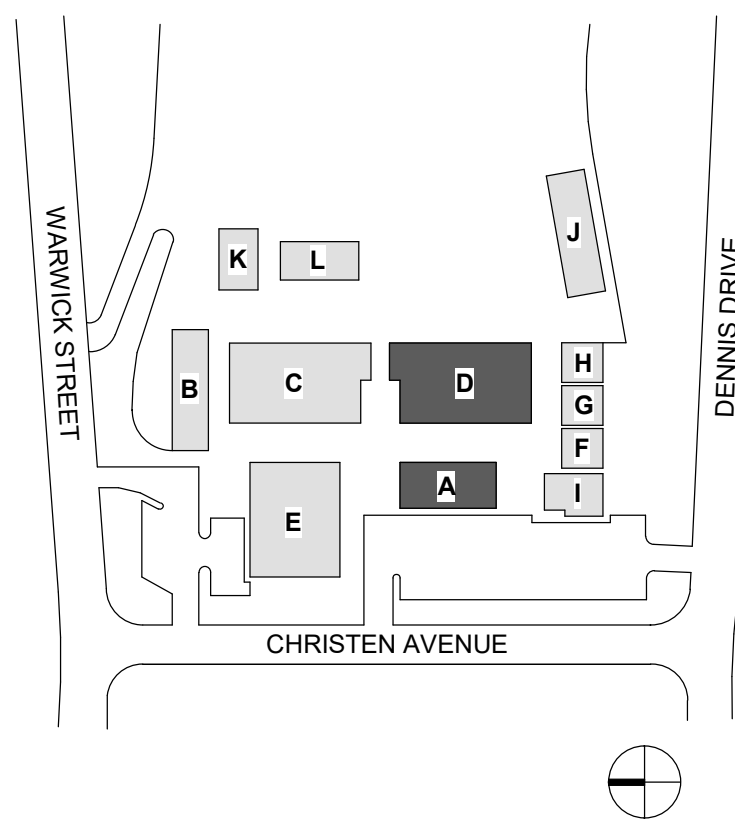

This document is the property of the Owner and is not to be used without their written permission.

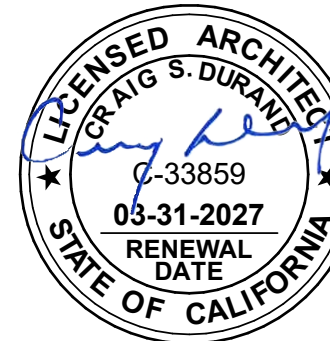

HY HIBSER YAMAUCHI Architects, Inc.
300 - 27th Street
Oakland, CA 94612
510.446.2222 tel; 510.446.2211 fax

HY Architects Project number: Project Number

Facility
SKYLINE ELEMENTARY SCHOOL
55 CHRISTEN AVE, DALY CITY, CA 94015

Project
HVAC REPLACEMENT

Sheet Title
FLOOR PLAN - BUILDING A & D

Client Project Number: 0000.0

Scale: As indicated

Drawn By: Author

Checked By: Checker

Issue Date: Issue Date

Revit Version: 2023

A2.04

Sheet 2 of 200

C:\Users\alidoc\Documents\6241 SFUSD Skyline ES HVAC_R05_Central_Archiect\A221N.rvt 2/18/2025 2:47:13 PM




IDENTIFICATION STAMP
DIV. OF THE STATE ARCHITECT

APP: 01-122566 INC:
REVIEWED FOR
SS ☒ FLS ☒ ACS ☐
DATE: 3/10/2026



Delta	Date	Revisions	By

KEY PLAN

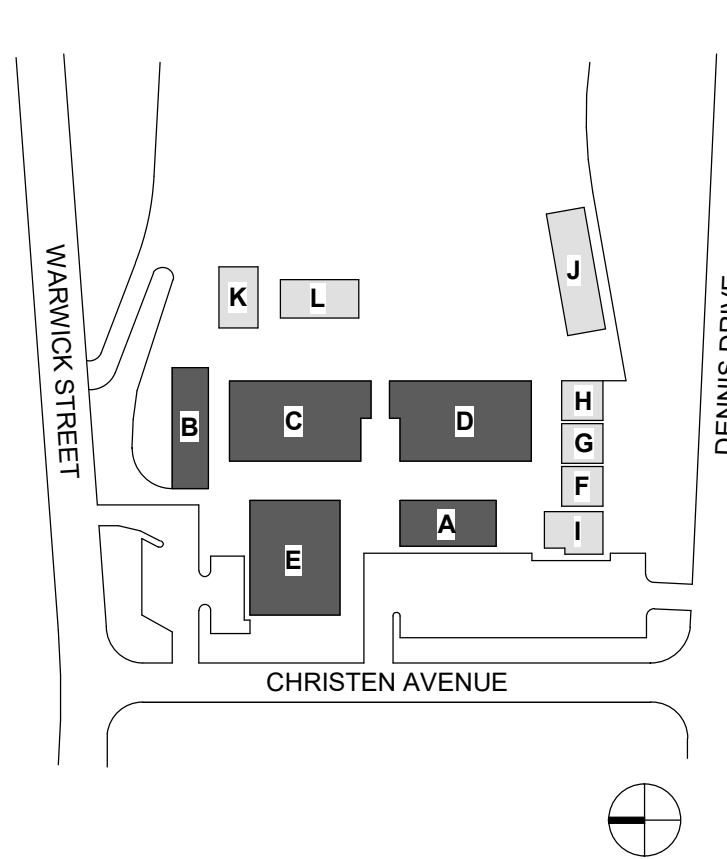

GENERAL NOTES

1. PRIOR TO START OF CONSTRUCTION CONTRACTOR TO FIELD VERIFY (E) CONDITIONS & NOTIFY ARCHITECT OF ANY DISCREPANCIES FROM THE PLANS.
2. PRIOR TO START OF CONSTRUCTION CONTRACTOR TO REMOVE & PROTECT ALL (E) EQUIPMENT & FURNITURE. RELEASE BACK TO THE FACILITY FOR FUTURE RE-USE UON OR UNLESS DIRECTED BY THE OWNER.
3. ALL DIMENSIONS SHALL BE FROM FACE OF STUD, UON. DIMENSIONS NOTED AS "CLR" REFER TO CLEAR DIMENSION FROM FACE OF FINISH.
4. WHEREVER THE TERM "ALIGN" IS SHOWN, CONTRACTOR TO ALIGN THE FACES OF WALL FINISH(ES).
5. PROTECT & MAINTAIN ALL (E) PARTITION RATINGS, UON.
6. PRESERVE & PROTECT (E) FINISHES THAT ARE TO REMAIN. WHERE DAMAGE OCCURS DURING CONSTRUCTION PATCH & REPAIR ALL WALLS, CEILING, AND FLOOR SURFACES TO MATCH (E), UON. IF FINISHES ARE DAMAGED BEYOND REPAIR & AN EXACT MATCH CANNOT BE PROCURED NOTIFY THE ARCHITECT IMMEDIATELY FOR DIRECTION ON REPLACEMENT FINISH SPECIFICATION. WALLS SHALL BE PAINTED TO THE NEAREST CORNER/ INTERSECTION & ALL OTHER FINISHES TO BE REPLACED AT THE NEAREST CORNER/ INTERSECTION FOR A SEAMLESS AESTHETIC.
7. REFER TO STRUCTURAL, MECHANICAL, AND ELECTRICAL SERIES SHEETS FOR ADDITIONAL INFORMATION. COORDINATE LOCATIONS OF WALL MOUNTED ACCESSORIES, EQUIPMENT, FURNITURE, SIGNAGE & THEIR ASSOCIATED BACKING WITH POWER/DATA, THERMOSTAT, LIGHT SWITCH & MISC. PANEL LOCATIONS PRIOR TO INSTALLATION.

DEMO NOTES

D2.02	DEMO (E) AC UNIT, TYP.
D2.03	DEMO (E) UNISTRUT, TYP.
D2.04	DEMO (E) ROOF CURB & PORTION OF ROOFING FOR PATCH, TYP.
D2.09	DEMO (E) FURNACE FLUE, SMD
D2.10	DEMO (E) GRAVITY VENT, SMD
D2.11	DEMO (E) CONDENSATE PIPING, SMD

KEYNOTES

02.02	(E) GUTTER, TYP.
02.04	(E) BUILT-UP ROOFING
02.07	(E) GRAVITY HOOD TO REMAIN, SMD

DEMO ROOF LEGEND

- (E) CASSETTE CONDENSING UNIT TO BE DEMOLISHED
- (E) MECHANICAL UNIT CURBS TO BE DEMOLISHED
- (E) B.U.R. AREA TO BE DEMOLISHED. SUBSTRATE TO REMAIN
- LINE OF (E) BUILDING FOOTPRINT BELOW
- (E) ROOF CONDUIT TO REMAIN


BLDG B

BLDG D

BLDG C


BLDG A

BLDG E

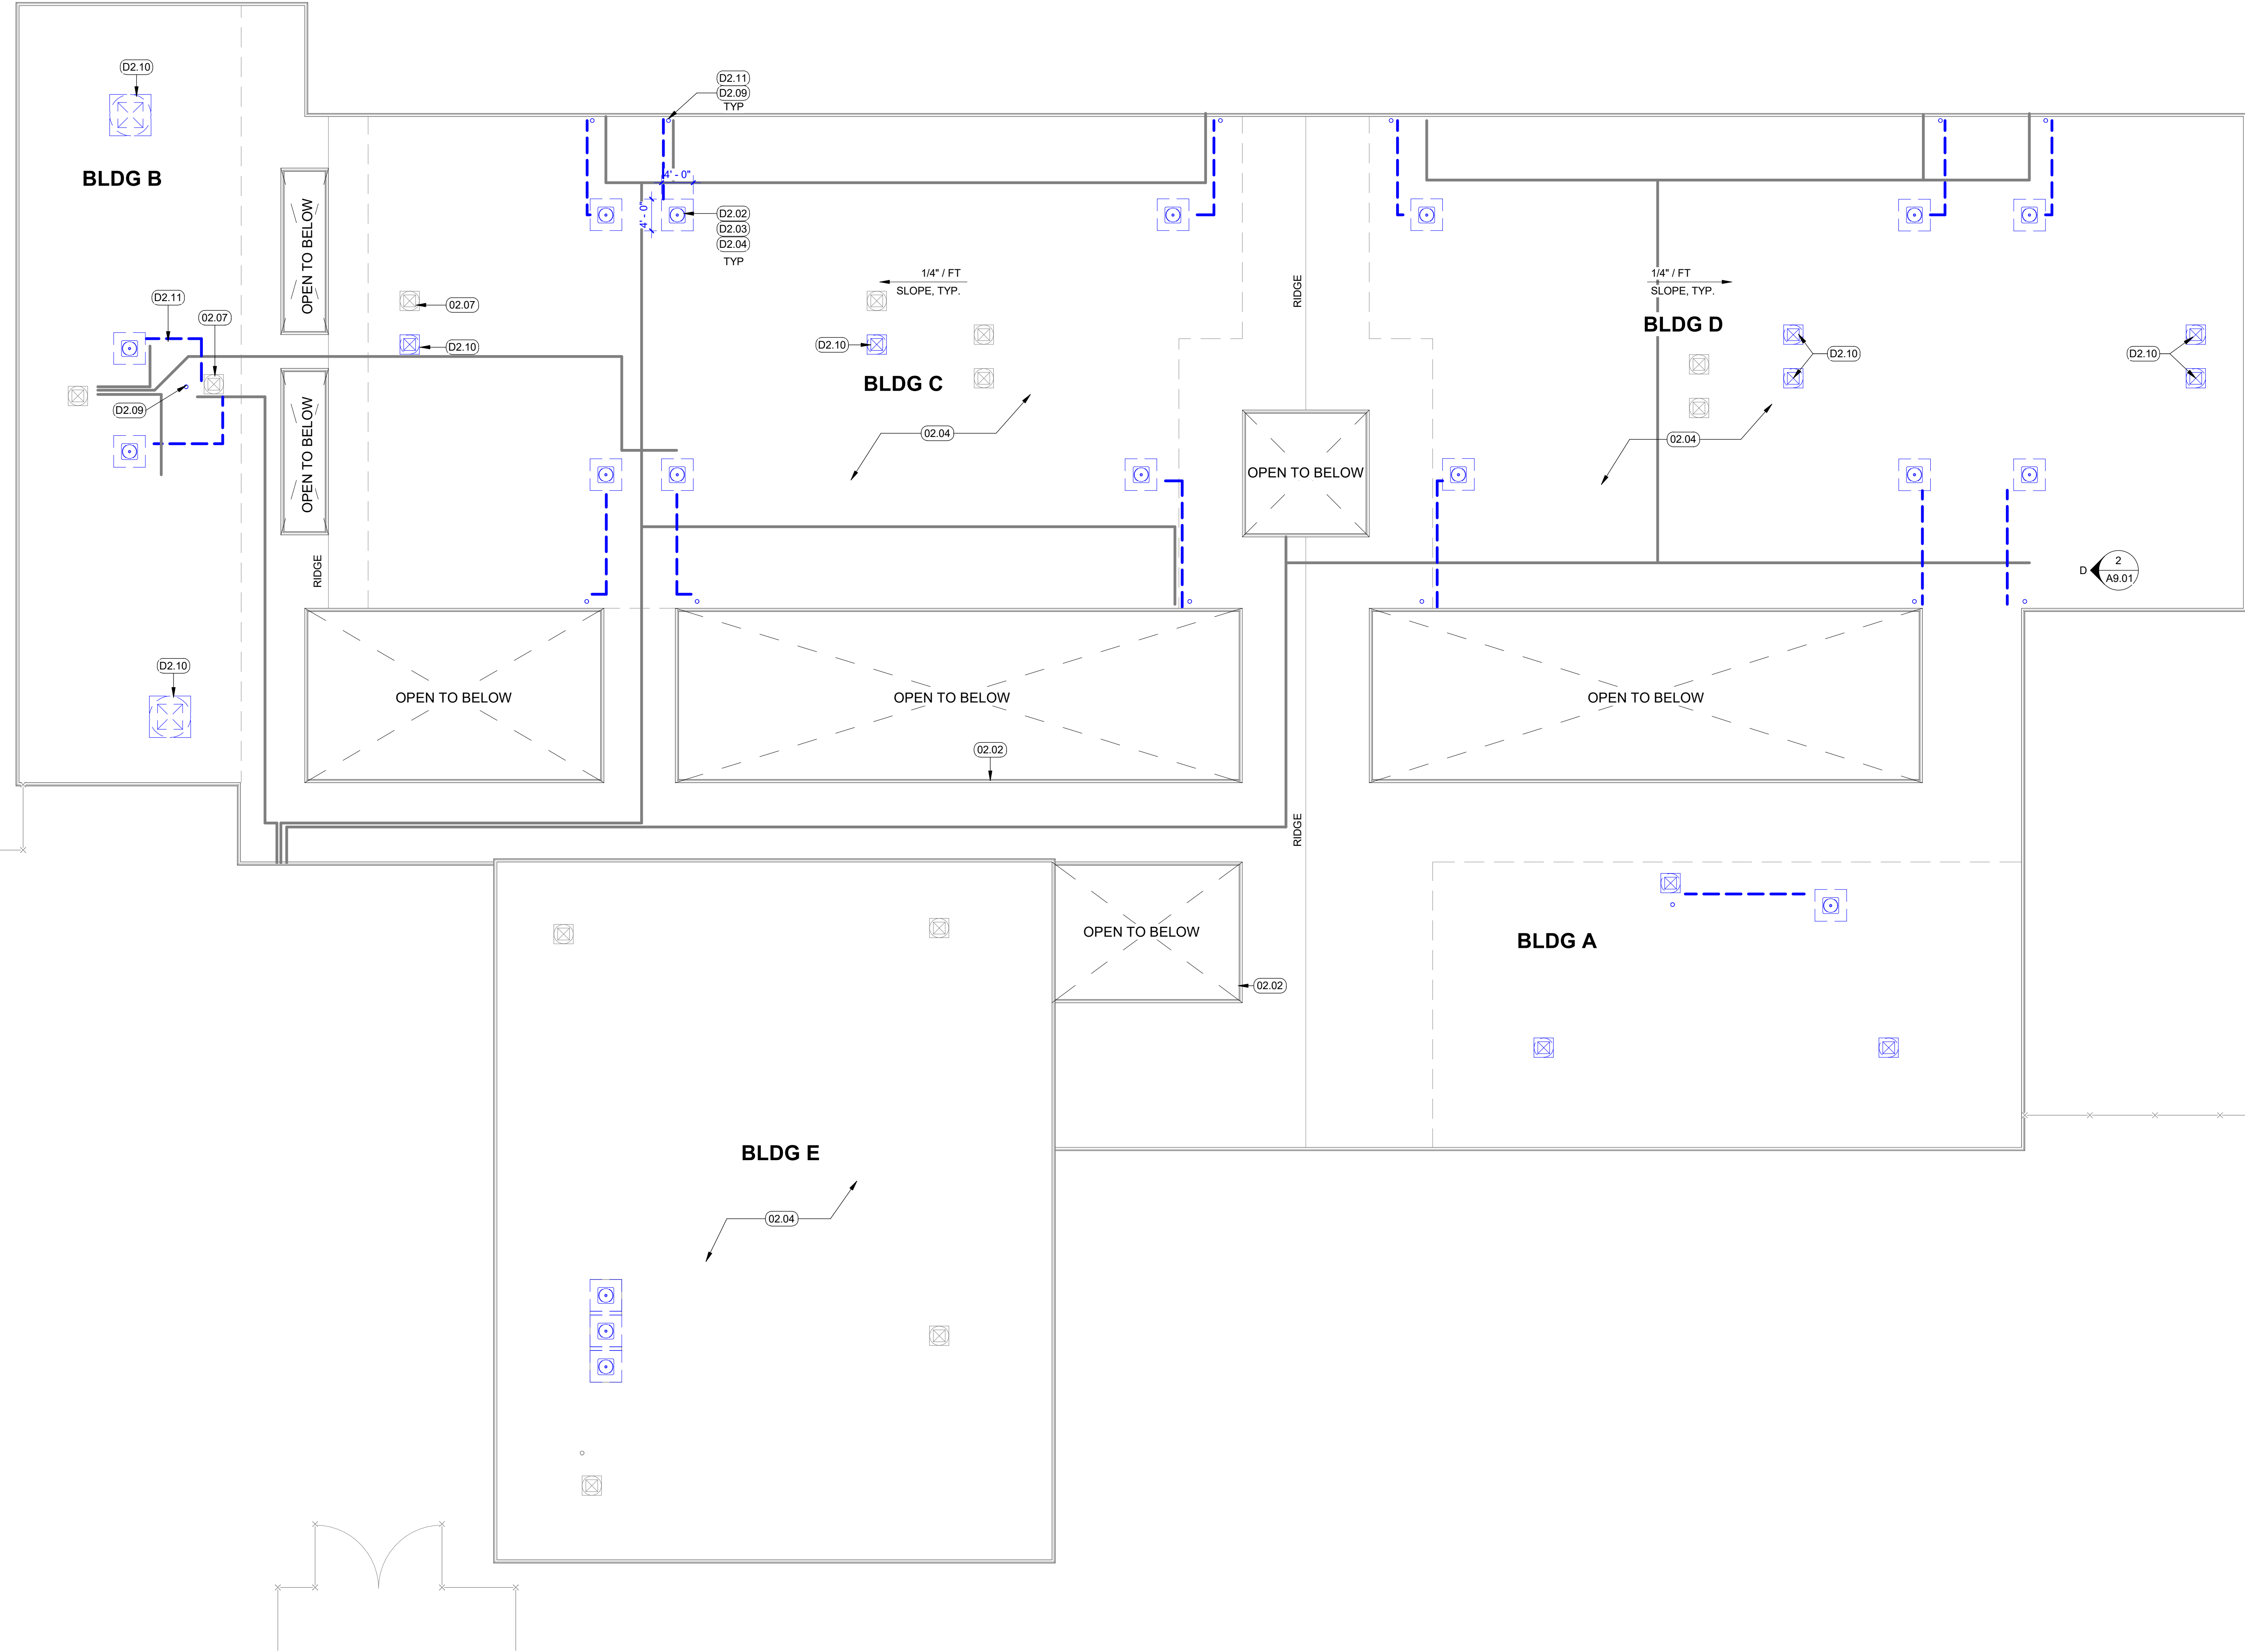

1 OVERALL ROOF PLAN - DEMO

1" = 10'-0"

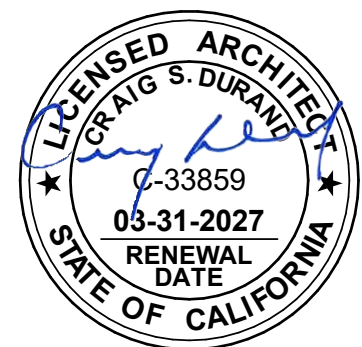

HY HIBSER YAMAUCHI
Architects, Inc.

300 - 27th Street
Oakland, CA 94612
510.446.2222 tel; 510.446.2211 fax

HY Architects Project number: Project Number

Facility
SKYLINE ELEMENTARY SCHOOL
55 CHRISTEN AVE, DALY CITY, CA 94015

Project
HVAC REPLACEMENT

Sheet Title
OVERALL ROOF PLAN - DEMO

Client Project Number: 0000.0

Scale: As indicated
Drawn By: Author
Checked By: Checker
Issue Date: Issue Date
Revit Version: 2023

Sheet
A2.21
2 of 200




IDENTIFICATION STAMP
DIV. OF THE STATE ARCHITECT

APP: 01-122566 INC:
REVIEWED FOR
SS ☒ FLS ☒ ACS ☐
DATE: 3/10/2026




Revisions			
Delta	Date	Revisions	By

KEY PLAN

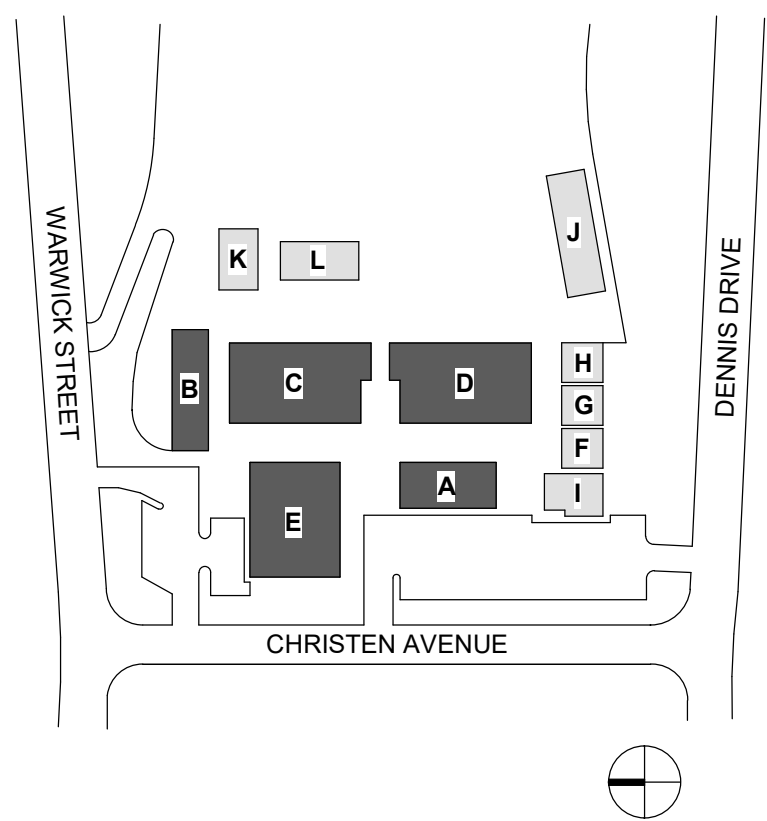

This document is the property of the Owner and is not to be used without their written permission

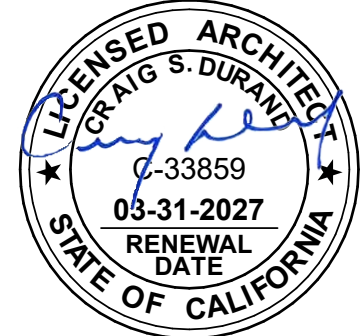

HY HIBSER YAMAUCHI
Architects, Inc.

300 - 27th Street
Oakland, CA 94612
510.446.2222 tel | 510.446.2211 fax

HY Architects Project number: Project Number

Facility
SKYLINE ELEMENTARY SCHOOL
55 CHRISTEN AVE, DALY CITY, CA 94015

Project
HVAC REPLACEMENT

Sheet Title
OVERALL ROOF PLAN - NEW

Client Project Number: 0000.0

Scale: As indicated
Drawn By: Author
Checked By: Checker
Issue Date: Issue Date
Revit Version: 2023

Sheet
A2.22
Sheet 2 of 200


GENERAL NOTES

1. PRIOR TO START OF CONSTRUCTION CONTRACTOR TO FIELD VERIFY (E) CONDITIONS & NOTIFY ARCHITECT OF ANY DISCREPANCIES FROM THE PLANS.
2. PRIOR TO START OF CONSTRUCTION CONTRACTOR TO REMOVE & PROTECT ALL (E) EQUIPMENT & FURNITURE. RELEASE BACK TO THE FACILITY FOR FUTURE RE-USE UON OR UNLESS DIRECTED BY THE OWNER.
3. ALL DIMENSIONS SHALL BE FROM FACE OF STUD, UON. DIMENSIONS NOTED AS "CLR" REFER TO CLEAR DIMENSION FROM FACE OF FINISH.
4. WHEREVER THE TERM "ALIGN" IS SHOWN, CONTRACTOR TO ALIGN THE FACES OF WALL FINISH(ES).
5. PROTECT & MAINTAIN ALL (E) PARTITION RATINGS, UON.
6. PRESERVE & PROTECT (E) FINISHES THAT ARE TO REMAIN. WHERE DAMAGE OCCURS DURING CONSTRUCTION PATCH & REPAIR ALL WALLS, CEILING, AND FLOOR SURFACES TO MATCH (E), UON. IF FINISHES ARE DAMAGED BEYOND REPAIR & AN EXACT MATCH CANNOT BE PROCURED NOTIFY THE ARCHITECT IMMEDIATELY FOR DIRECTION ON REPLACEMENT FINISH SPECIFICATION. WALLS SHALL BE PAINTED TO THE NEAREST CORNER/ INTERSECTION & ALL OTHER FINISHES TO BE REPLACED AT THE NEAREST CORNER/ INTERSECTION FOR A SEAMLESS AESTHETIC.
7. REFER TO STRUCTURAL, MECHANICAL, AND ELECTRICAL SERIES SHEETS FOR ADDITIONAL INFORMATION. COORDINATE LOCATIONS OF WALL MOUNTED ACCESSORIES, EQUIPMENT, FURNITURE, SIGNAGE & THEIR ASSOCIATED BACKING WITH POWER/DATA, THERMOSTAT, LIGHT SWITCH & MISC. PANEL LOCATIONS PRIOR TO INSTALLATION.

KEYNOTES

02.02	(E) GUTTER, TYP.
02.04	(E) BUILT-UP ROOFING
23.02	SPLIT SYSTEM CONDENSING UNIT, SMD
23.04	GRAVITY HOOD, SMD
23.05	CONDENSATE LINE, SMD
23.06	(N) VENT AT (E) OPENING, SMD

ROOF LEGEND

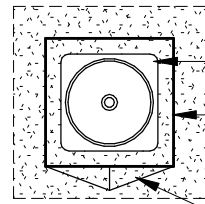



SPLIT SYSTEM CONDENSING UNIT, SMD
MECHANICAL UNIT CURB, SEE DETAIL 19 / A9.01
ROOF PATCH, SEE DETAIL 12 / A9.01
CRICKET, SEE DETAIL 17 / A9.01



LINE OF (E) BUILDING FOOTPRINT BELOW



(E) ROOF CONDUIT TO REMAIN

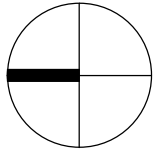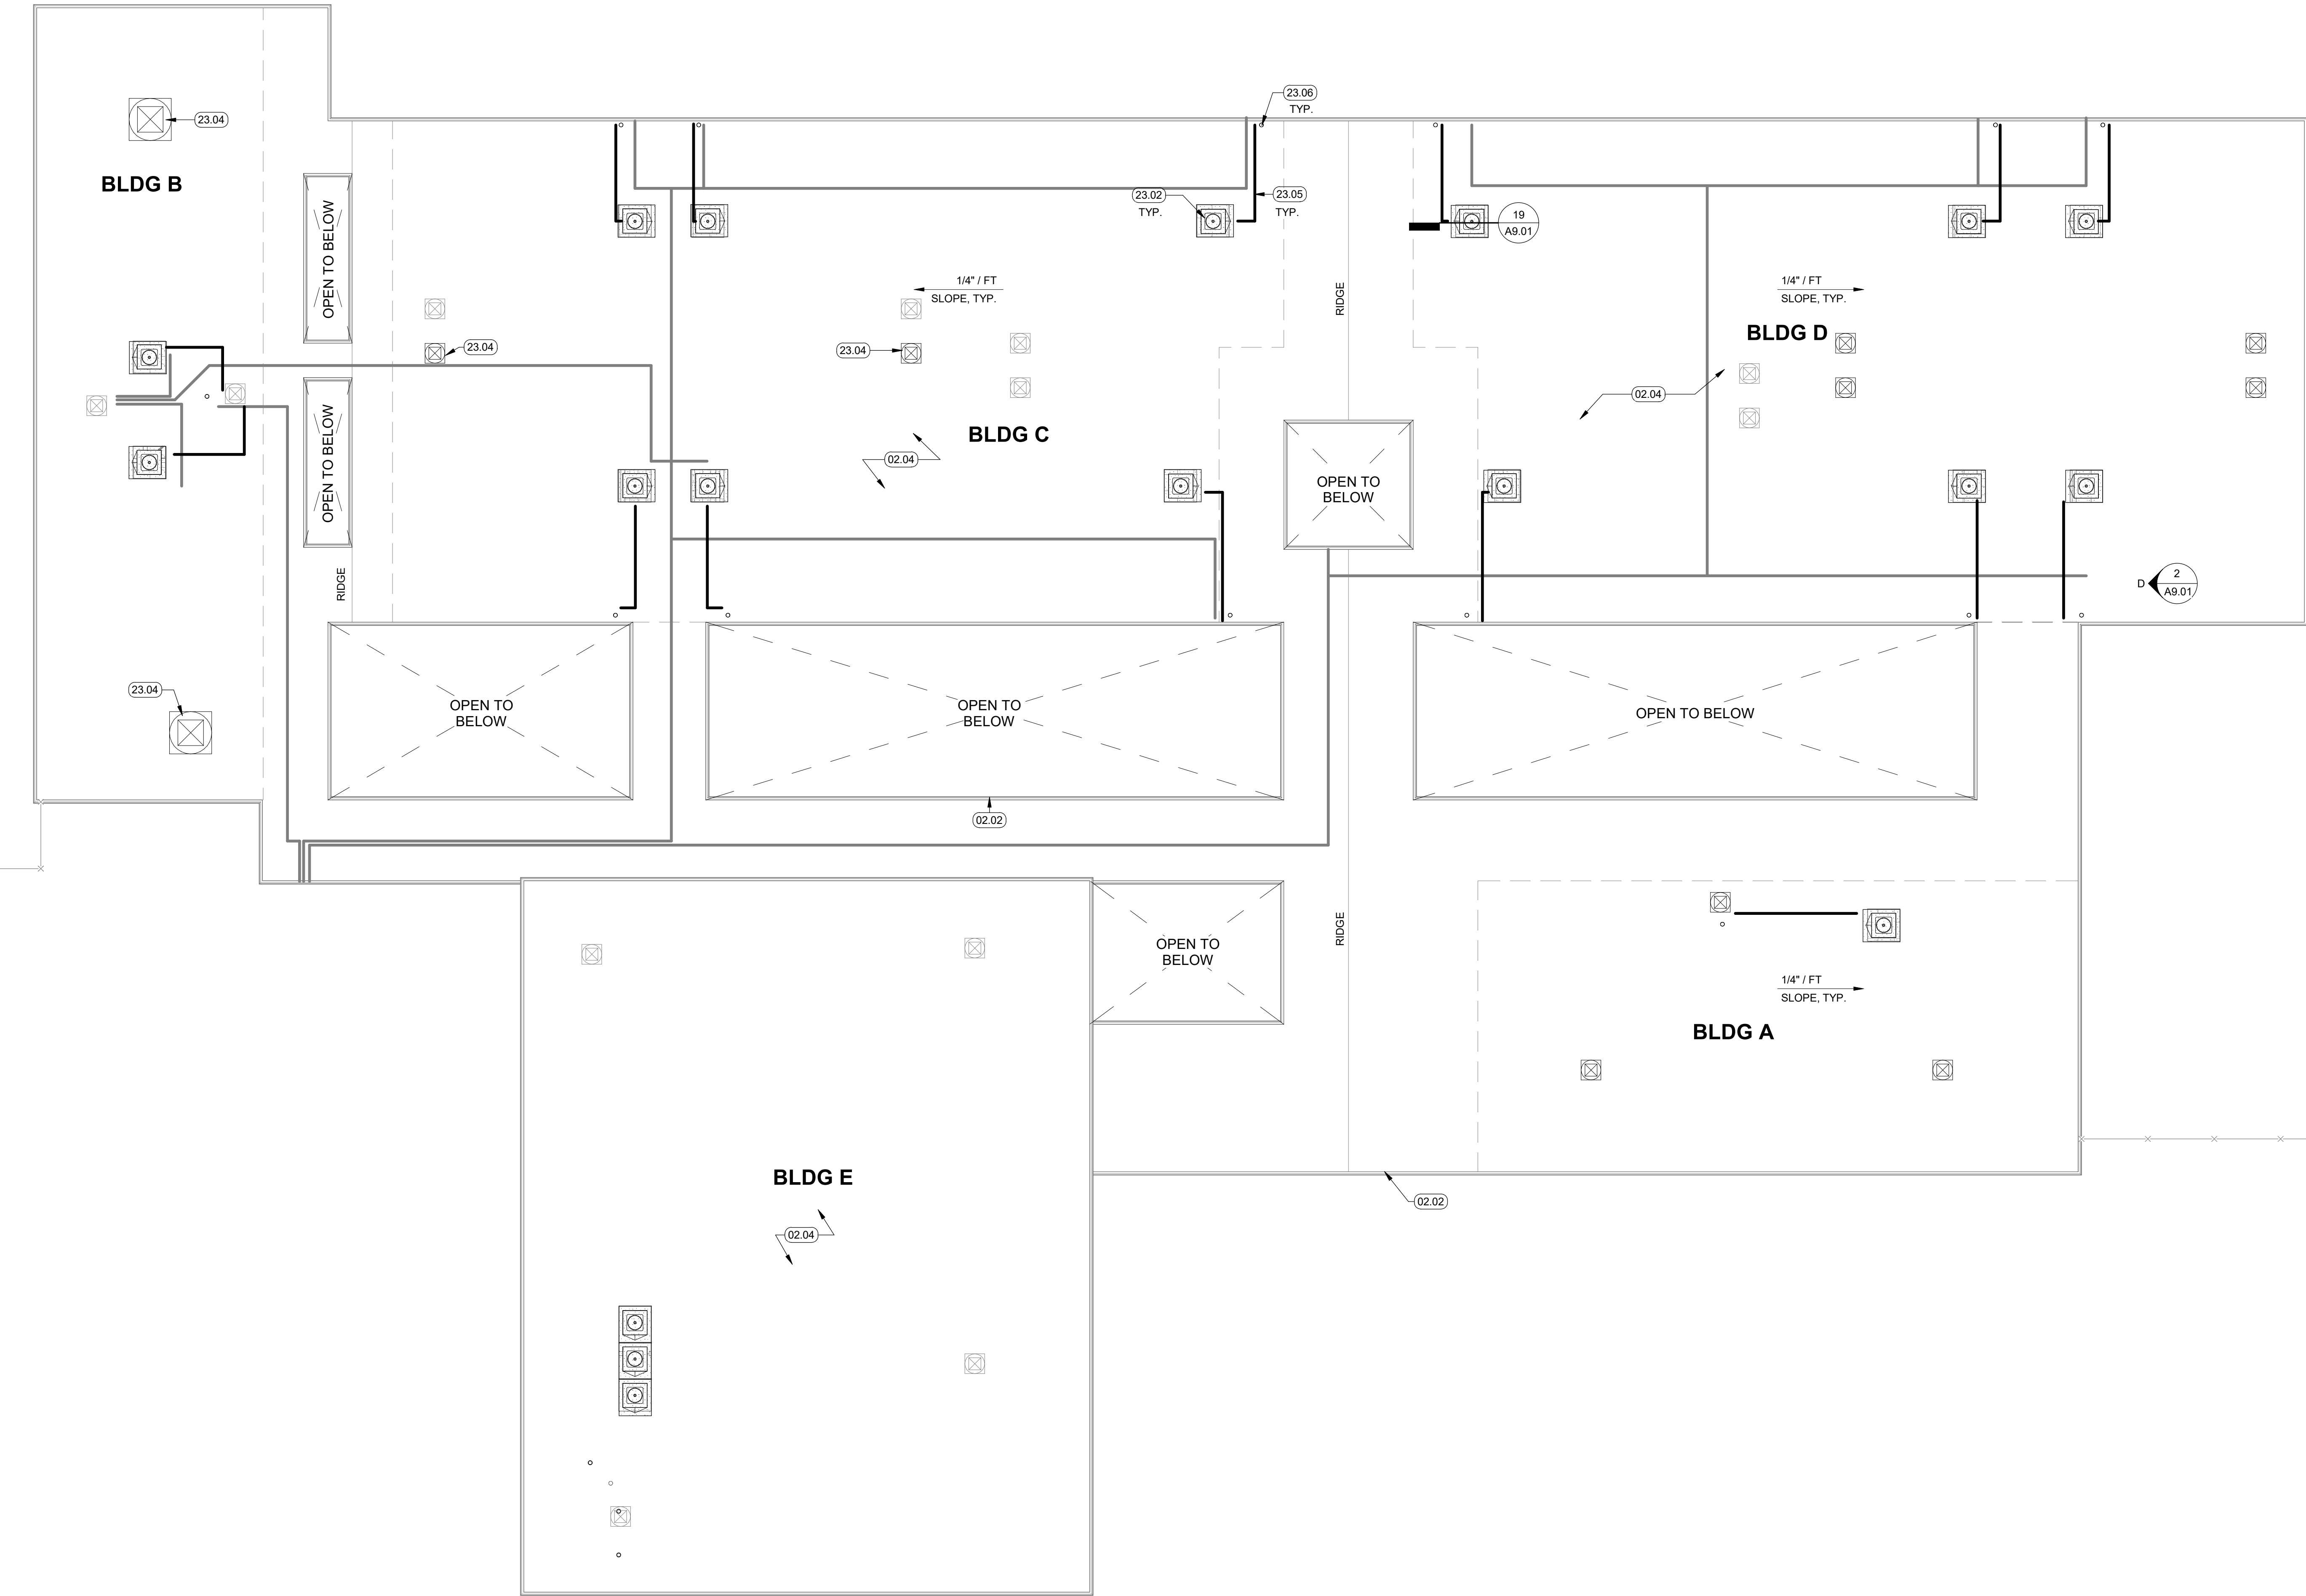


1 ROOF PLAN - OVERALL

1" = 10'-0"

C:\Users\aliback\Documents\6244 Skyline ES HVAC_R05_Central_Aliback\AZLN.rvt

2/18/2025 2:07:14 PM

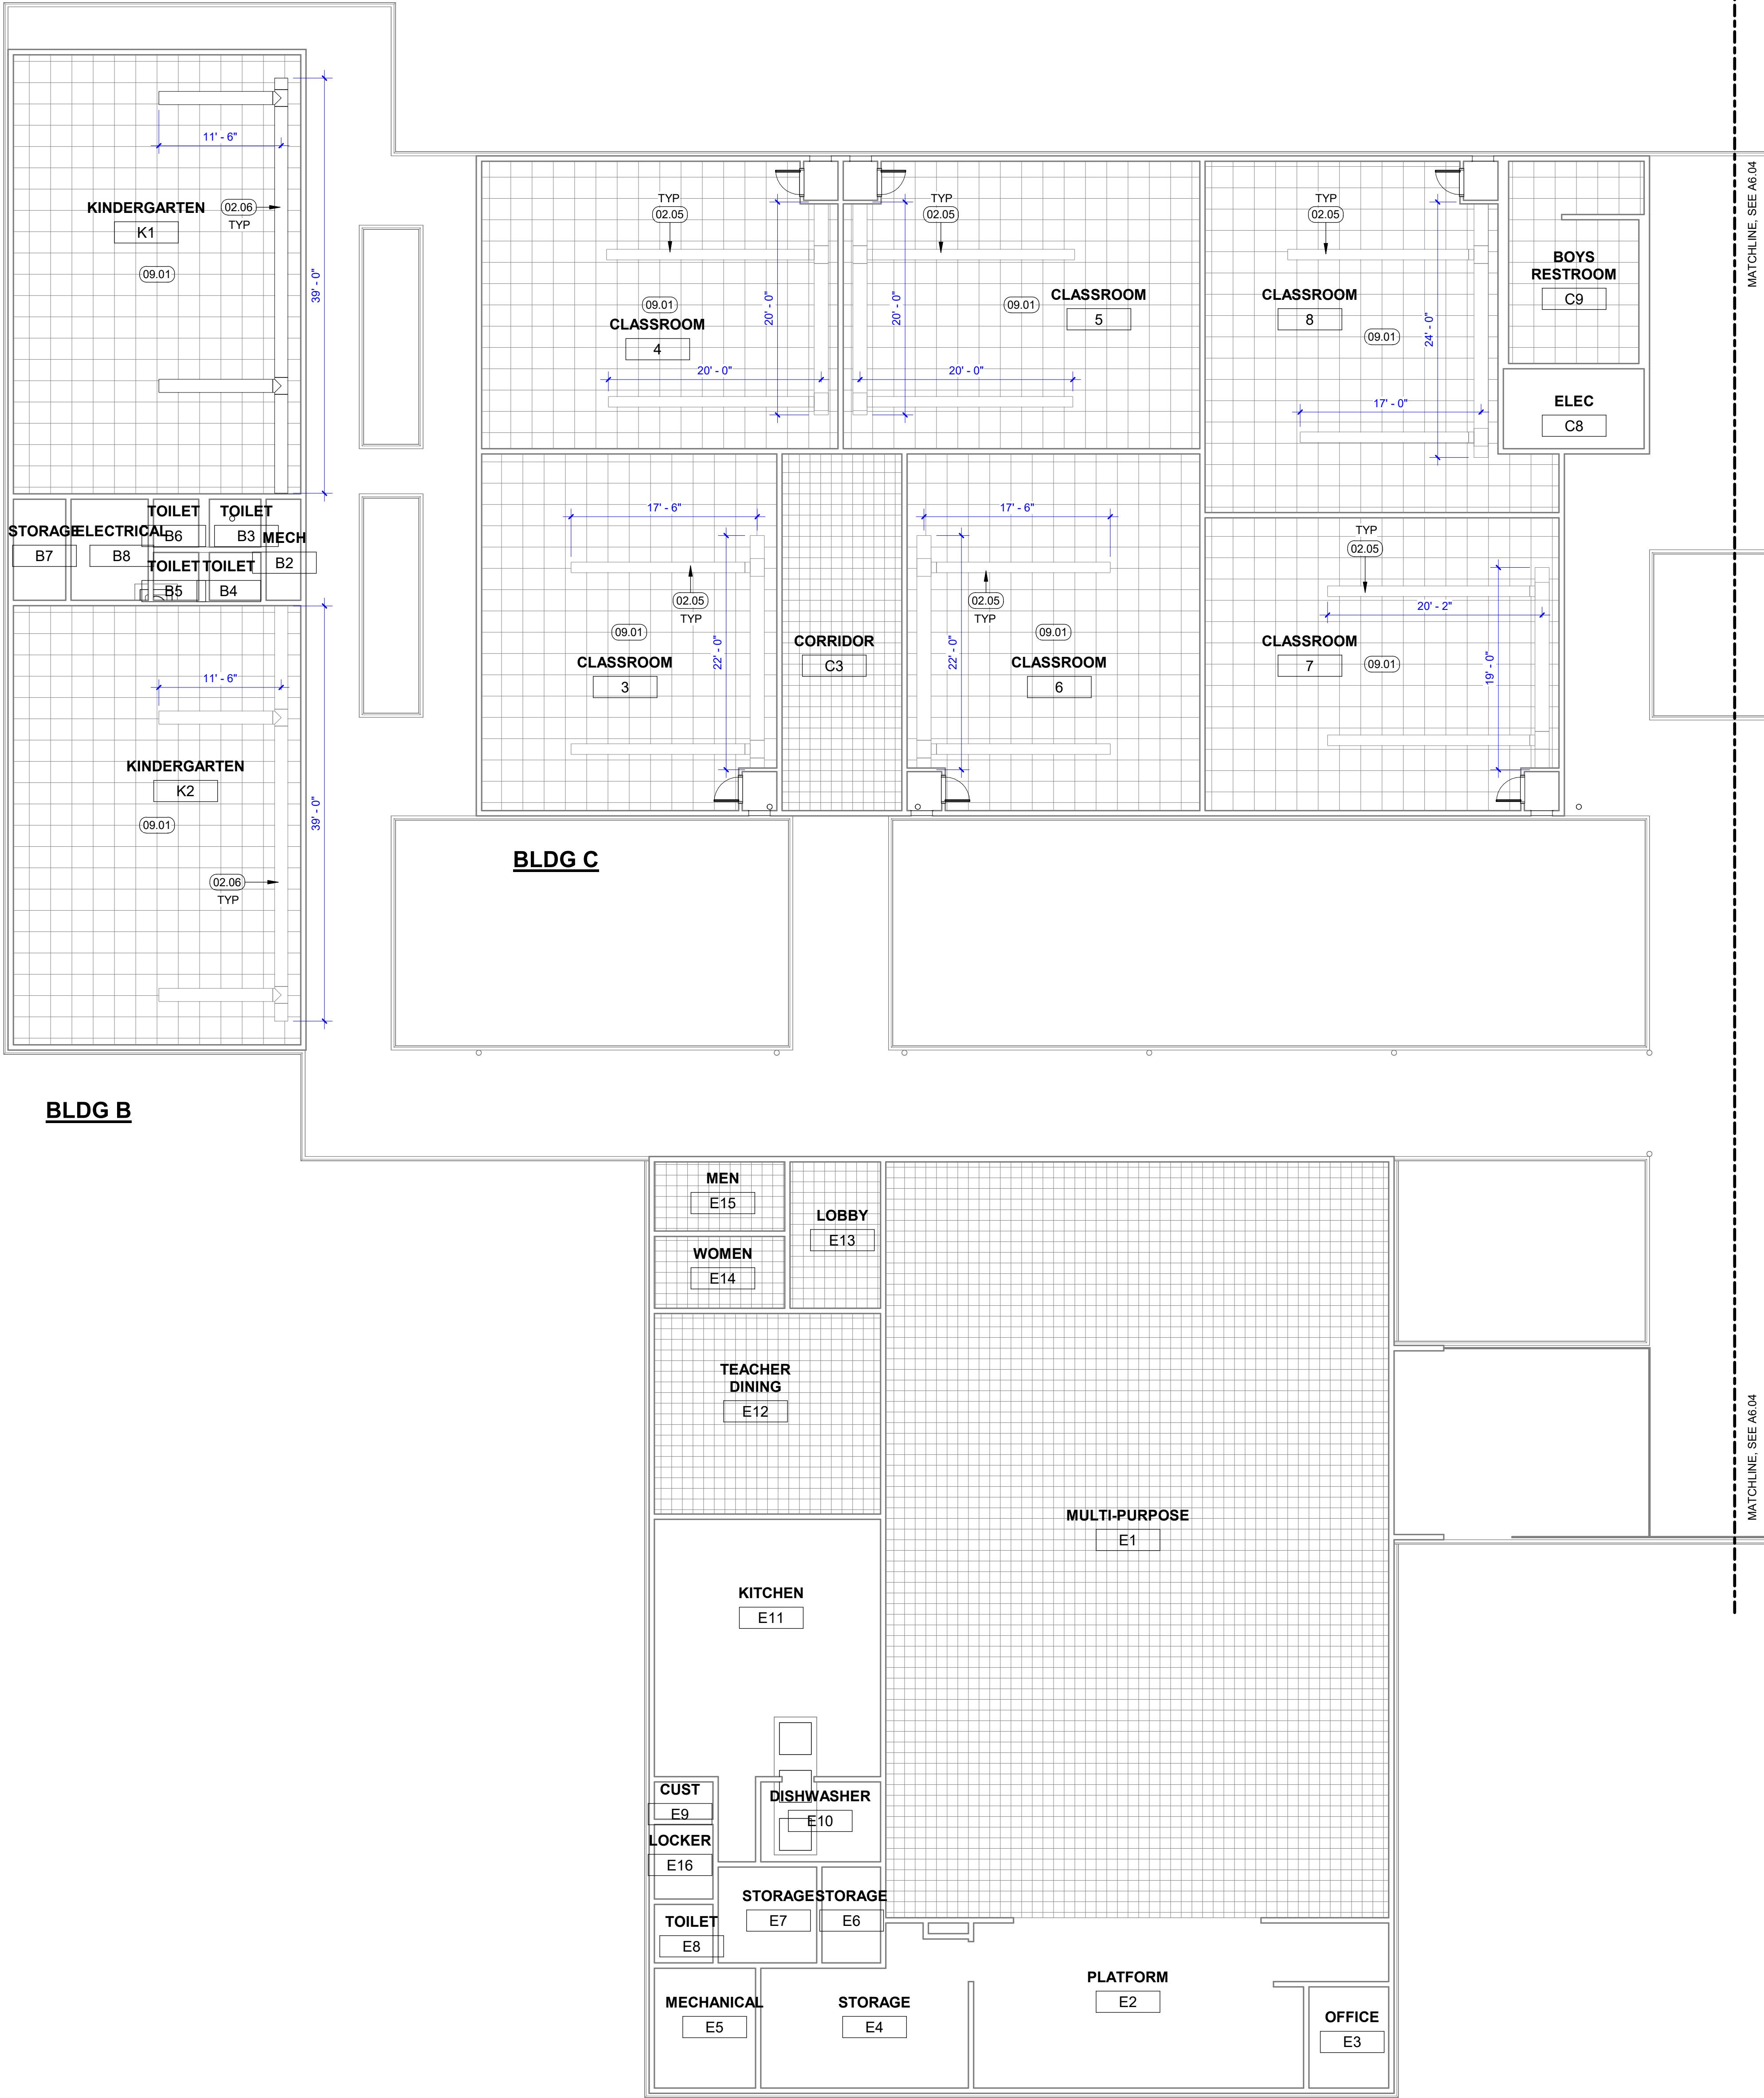

GENERAL NOTES


1. PRIOR TO START OF CONSTRUCTION CONTRACTOR TO FIELD VERIFY (E) CONDITIONS & NOTIFY ARCHITECT OF ANY DISCREPANCIES FROM THE PLANS.
2. PRIOR TO START OF CONSTRUCTION CONTRACTOR TO REMOVE & PROTECT ALL (E) EQUIPMENT & FURNITURE. RELEASE BACK TO THE FACILITY FOR FUTURE RE-USE UON OR UNLESS DIRECTED BY THE OWNER.
3. ALL DIMENSIONS SHALL BE FROM FACE OF STUD, UON. DIMENSIONS NOTED AS "CLR" REFER TO CLEAR DIMENSION FROM FACE OF FINISH.
4. WHEREVER THE TERM "ALIGN" IS SHOWN, CONTRACTOR TO ALIGN THE FACES OF WALL FINISH(ES).
5. PROTECT & MAINTAIN ALL (E) PARTITION RATINGS, UON.
6. PRESERVE & PROTECT (E) FINISHES THAT ARE TO REMAIN. WHERE DAMAGE OCCURS DURING CONSTRUCTION PATCH & REPAIR ALL WALLS, CEILING, AND FLOOR SURFACES TO MATCH (E), UON. IF FINISHES ARE DAMAGED BEYOND REPAIR & AN EXACT MATCH CANNOT BE PROCURED NOTIFY THE ARCHITECT IMMEDIATELY FOR DIRECTION ON REPLACEMENT FINISH SPECIFICATION. WALLS SHALL BE PAINTED TO THE NEAREST CORNER/ INTERSECTION & ALL OTHER FINISHES TO BE REPLACED AT THE NEAREST CORNER/ INTERSECTION FOR A SEAMLESS AESTHETIC.
7. REFER TO STRUCTURAL, MECHANICAL, AND ELECTRICAL SERIES SHEETS FOR ADDITIONAL INFORMATION. COORDINATE LOCATIONS OF WALL MOUNTED ACCESSORIES, EQUIPMENT, FURNITURE, SIGNAGE & THEIR ASSOCIATED BACKING WITH POWER/DATA, THERMOSTAT, LIGHT SWITCH & MISC. PANEL LOCATIONS PRIOR TO INSTALLATION.

KEYNOTES

02.05	CLEAN (E) DUCT TO REMAIN, TYP. SEE BID ALT.
02.06	CLEAN (E) DUCT TO REMAIN.
09.01	REMOVE & REINSTALL (E) 2X2' CEILING TILES AS NEEDED TO COMPLETE WORK. KEEP IN GOOD CONDITION.


BID ALTERNATES

- BASE BID - CLEAN ALL (E) DUCTWORK
1. BID ALTERNATE - REPLACE (E) DUCTWORK IN BUILDING C AND D. CLEAN ALL OTHER (E) DUCTWORK IN BLDG A, B, E PER BASE BID.

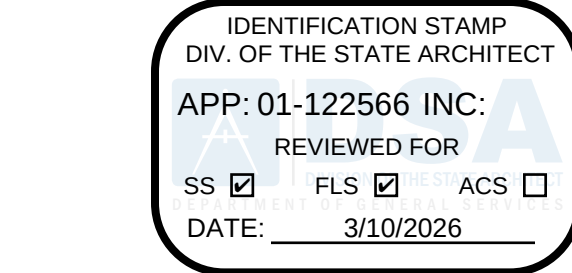


Revisions	Delta	Date	Revisions	By

KEY PLAN

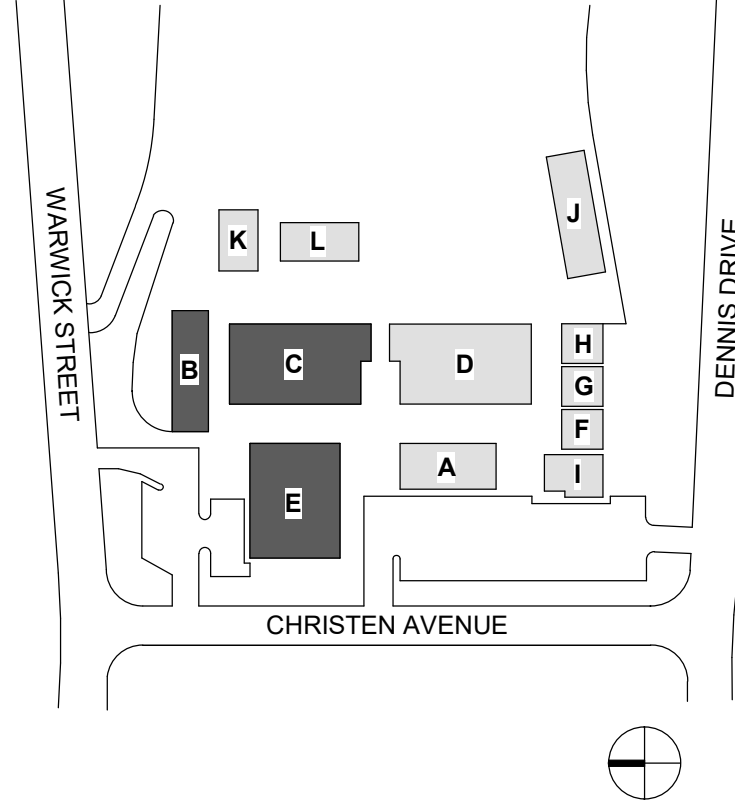

This document is the property of the Owner and is not to be used without their written permission

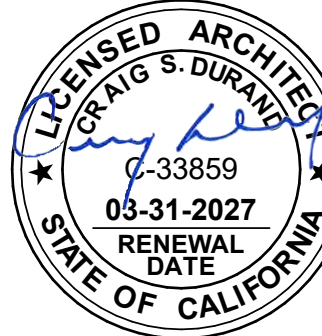

HY Architects Project number: SKYLINE ELEMENTARY SCHOOL

Facility: 55 CHRISTEN AVE, DALY CITY, CA 94015

Project: HVAC REPLACEMENT

Sheet Title: REFLECTED CEILING PLANS - BLDG B, C, & E

Client Project Number: 0000.0

Scale: As indicated

Drawn By: Author

Checked By: Checker

Issue Date: Issue Date


Revit Version: 2023

A6.03

Sheet 2 of 200

1 RCP - BLDG B, C, & E

1/8" = 1'-0"

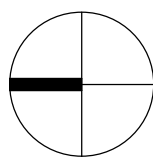



IDENTIFICATION STAMP
DIV. OF THE STATE ARCHITECT

APP: 01-122566 INC:

REVIEWED FOR


SS ☒ FLS ☒ ACS ☐

DATE: 3/10/2026



Revisions	Delta	Date	Revisions	By

KEY PLAN

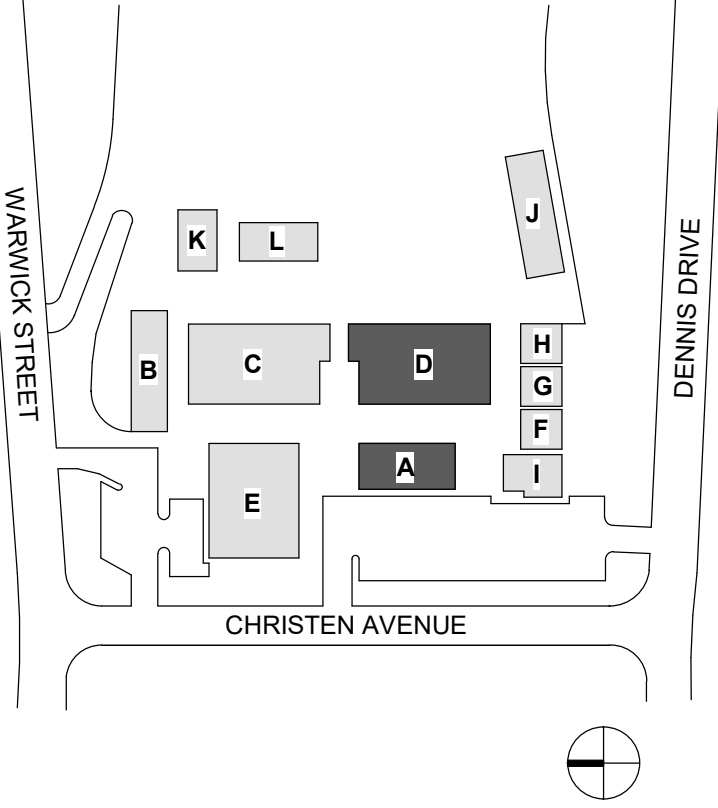



KEYNOTES

02.05	CLEAN (E) DUCT TO REMAIN, TYP. SEE BID ALT.
09.01	REMOVE & REINSTALL (E) 2X2' CEILING TILES AS NEEDED TO COMPLETE WORK. KEEP IN GOOD CONDITION.


BID ALTERNATES

BASE BID - CLEAN ALL (E) DUCTWORK

1. BID ALTERNATE - REPLACE (E) DUCTWORK IN BUILDING C AND D. CLEAN ALL OTHER (E) DUCTWORK IN BLDG A, B, E PER BASE BID.

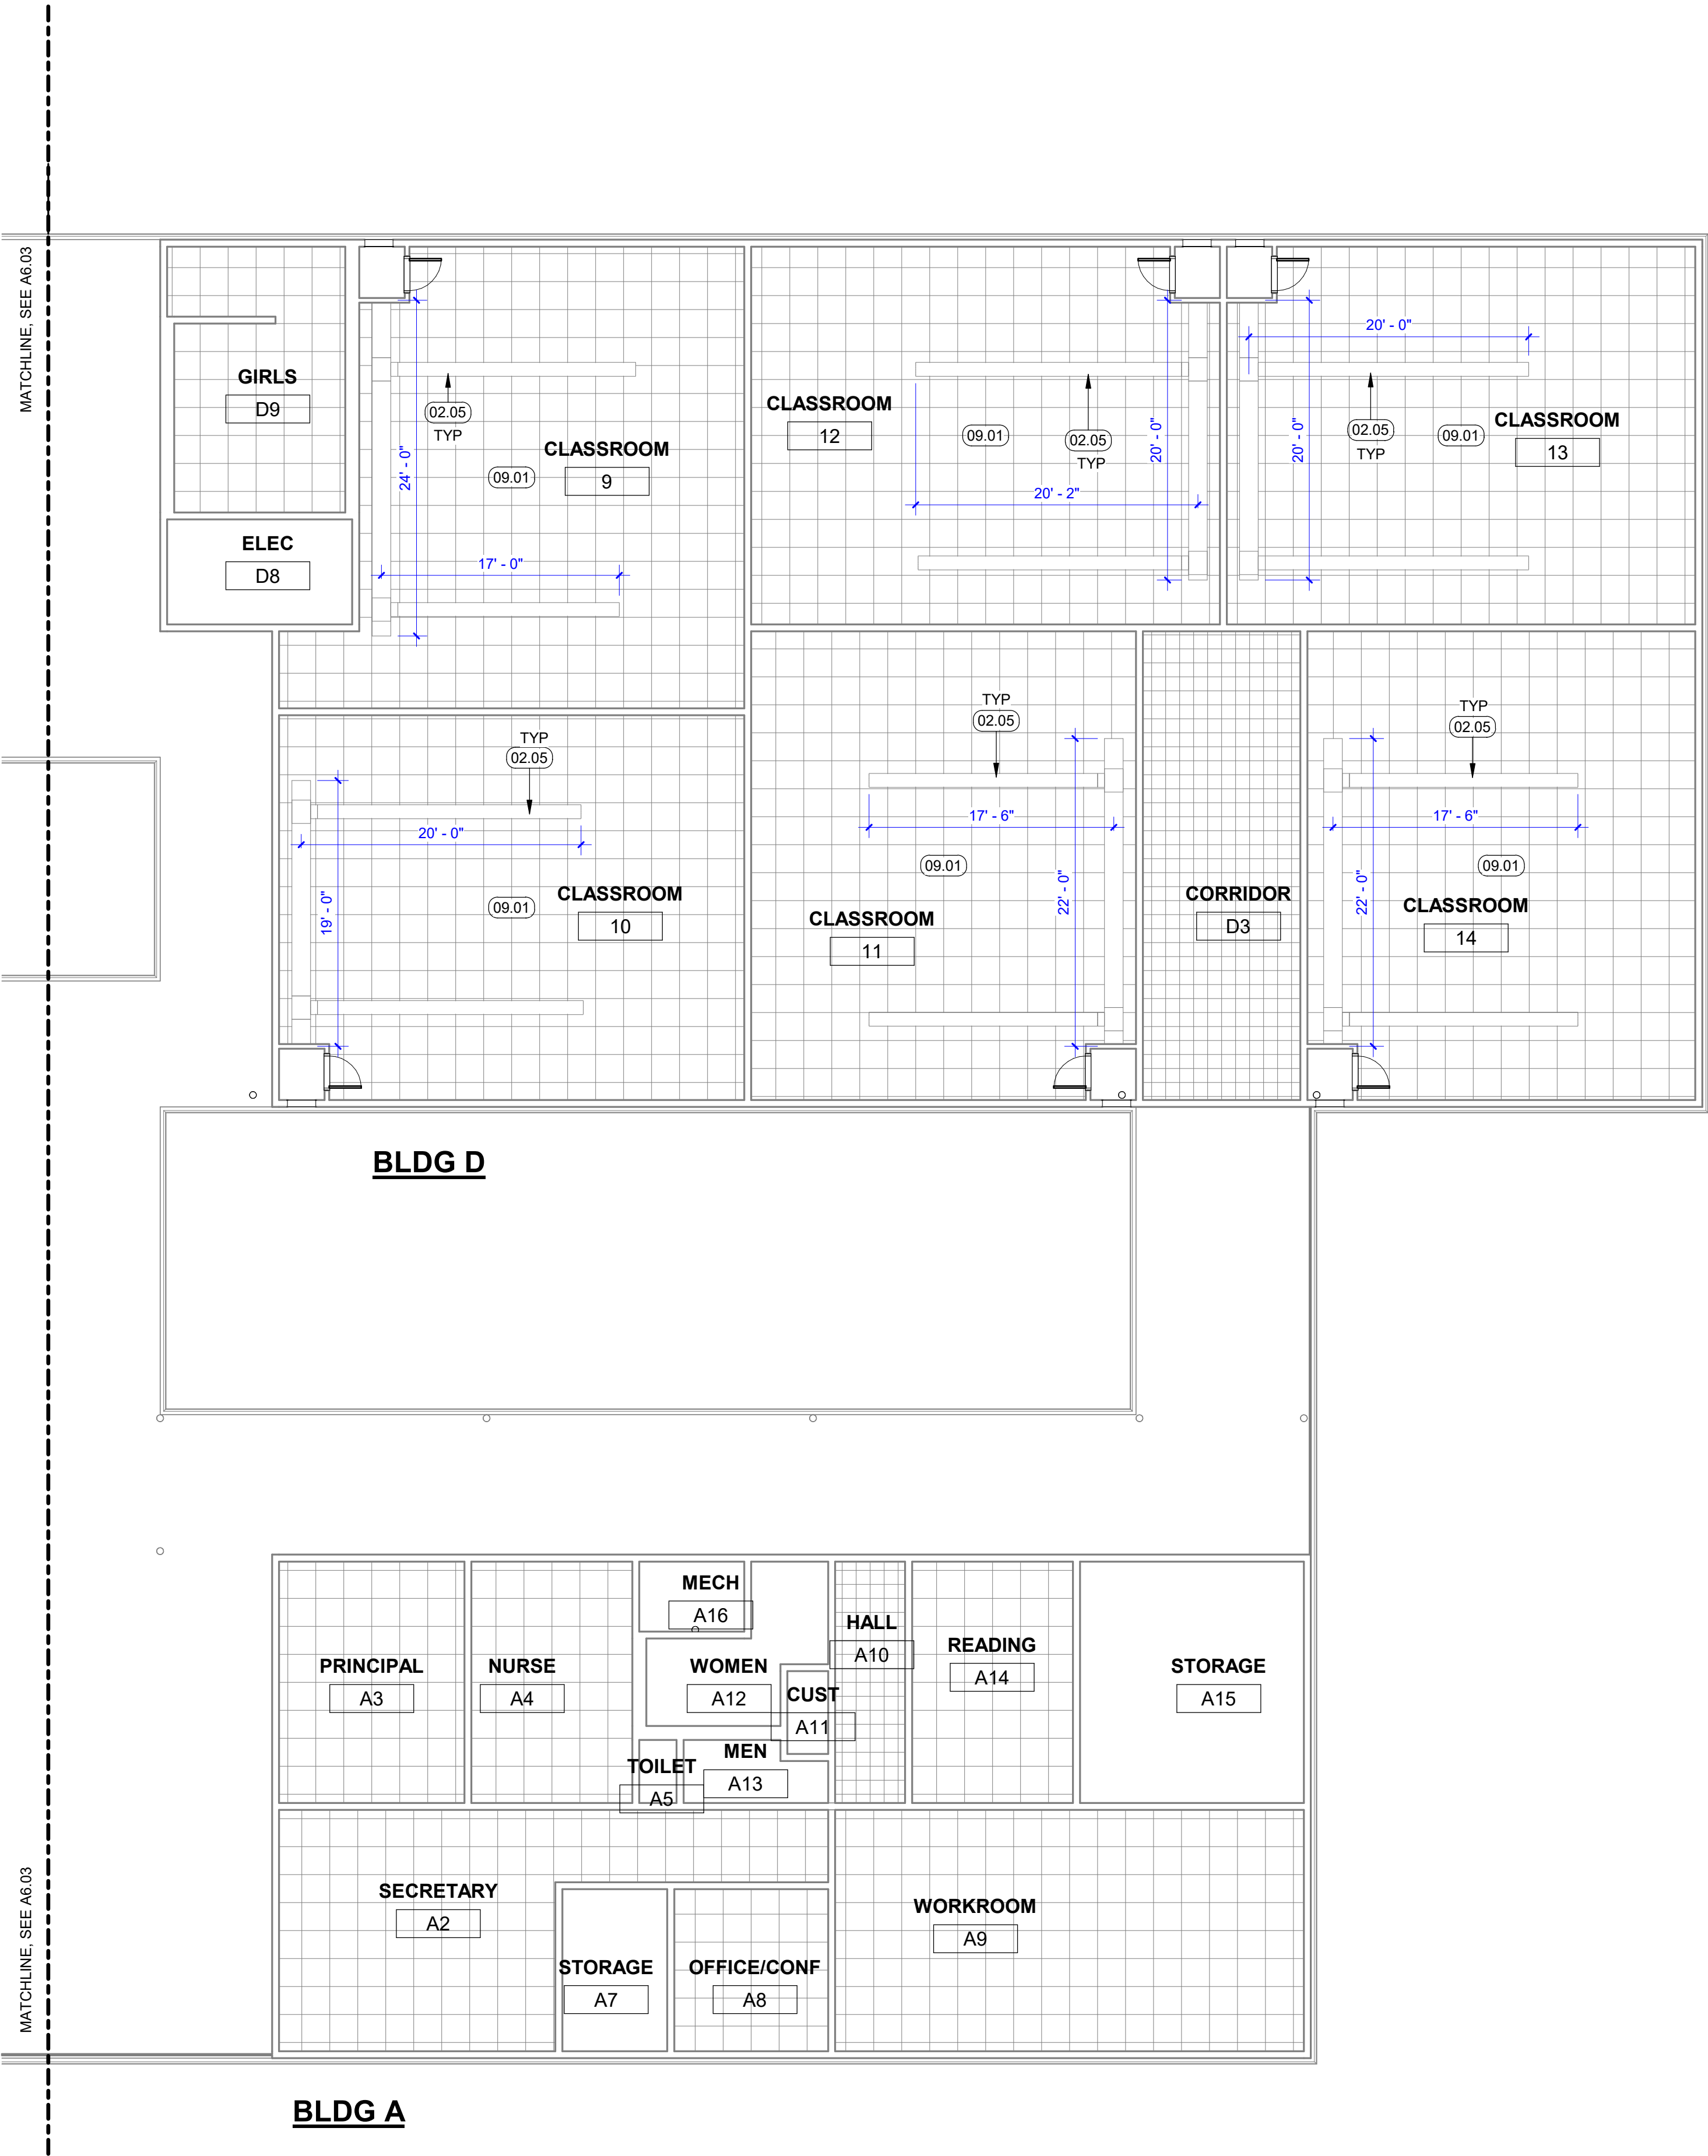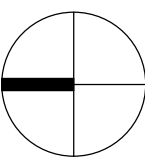

This document is the property of the Owner and is not to be used without their written permission.

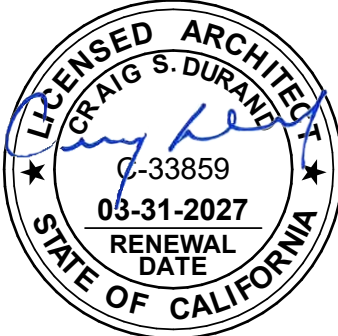

HY HIBSER YAMAUCHI
Architects, Inc.

300 - 27th Street
Oakland, CA 94612
510.446.2222 tel; 510.446.2211 fax

HY Architects Project number: Skyline Elementary School
Project Number: 0000.0

Facility: SKYLINE ELEMENTARY SCHOOL
55 CHRISTEN AVE, DALY CITY, CA 94015

Project: HVAC REPLACEMENT

Sheet Title: REFLECTED CEILING PLANS -
BLDG A & D

Client Project Number: 0000.0

Scale:	As indicated	Sheet
Drawn By:	Author	
Checked By:	Checker	
Issue Date:	Issue Date	
Revit Version:	2023	Sheet 2 of 200





IDENTIFICATION STAMP
DIV. OF THE STATE ARCHITECT
APP: 01-122566 INC:
REVIEWED FOR
SS ☒ FLS ☒ ACS ☐
DATE: 3/10/2026



Revisions	Delta	Date	Revisions	By

LOUVER SCHEDULE				
TYPE	SIZE	LOCATION	INSECT SCREEN	Count
1	24"x18"	EXTERIOR	YES	14
2	24"x24"	EXTERIOR	YES	15
3	48"x84"	EXTERIOR	YES	1

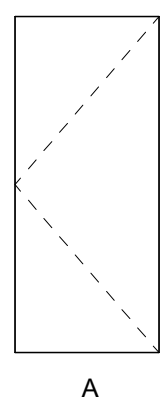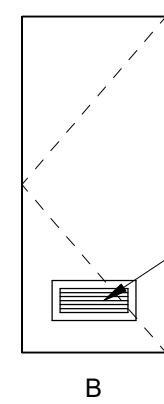

LOUVER TYPE 2, SEE SCHED

DOOR LEGEND


1/4" = 1'-0"

DOOR MARK	DOOR AND FRAME SCHEDULE											REMARKS	SIGNAGE	
	DOOR				FRAME						DOOR HARDWARE		TYPE	SIGN TEXT/ROOM
	NOMINAL SIZE		MATERIAL	DOOR TYPE	MATERIAL	TYPE	DETAILS							
	WIDTH	HEIGHT					HEAD	JAMB	SILL					
3	2'- 3 1/2"	5'- 0"	WD	A	HM	1	10/A9.01	5/A9.01	5/A9.01	1				
4	2'- 3 1/2"	5'- 0"	WD	A	HM	1	10/A9.01	5/A9.01	5/A9.01	1				
5	2'- 3 1/2"	5'- 0"	WD	A	HM	1	10/A9.01	5/A9.01	5/A9.01	1				
6	2'- 3 1/2"	5'- 0"	WD	A	HM	1	10/A9.01	5/A9.01	5/A9.01	1				
7	2'- 3 1/2"	5'- 0"	WD	A	HM	1	10/A9.01	5/A9.01	5/A9.01	1				
8	2'- 3 1/2"	5'- 0"	WD	A	HM	1	10/A9.01	5/A9.01	5/A9.01	1				
9	2'- 3 1/2"	5'- 0"	WD	A	HM	1	10/A9.01	5/A9.01	5/A9.01	1				
10	2'- 3 1/2"	5'- 0"	WD	A	HM	1	10/A9.01	5/A9.01	5/A9.01	1				
11	2'- 3 1/2"	5'- 0"	WD	A	HM	1	10/A9.01	5/A9.01	5/A9.01	1				
12	2'- 3 1/2"	5'- 0"	WD	A	HM	1	10/A9.01	5/A9.01	5/A9.01	1				
13	2'- 3 1/2"	5'- 0"	WD	A	HM	1	10/A9.01	5/A9.01	5/A9.01	1				
14	2'- 3 1/2"	5'- 0"	WD	A	HM	1	10/A9.01	5/A9.01	5/A9.01	1				
15	3'- 0"	7'- 0"	(E)	B	(E)	(E)	-	-	-	2				


DOOR HARDWARE

GROUP 1
3 EA HINGE, SBB1 4.5X4.5, 852, IVES
1 EA GASKETING, 188S-BK PSA, BK, ZERO
REINSTALL (E) DEADBOLT
REINSTALL (E) STRIKE PLATE


GROUP 2
HARDWARE EXISTING TO REMAIN

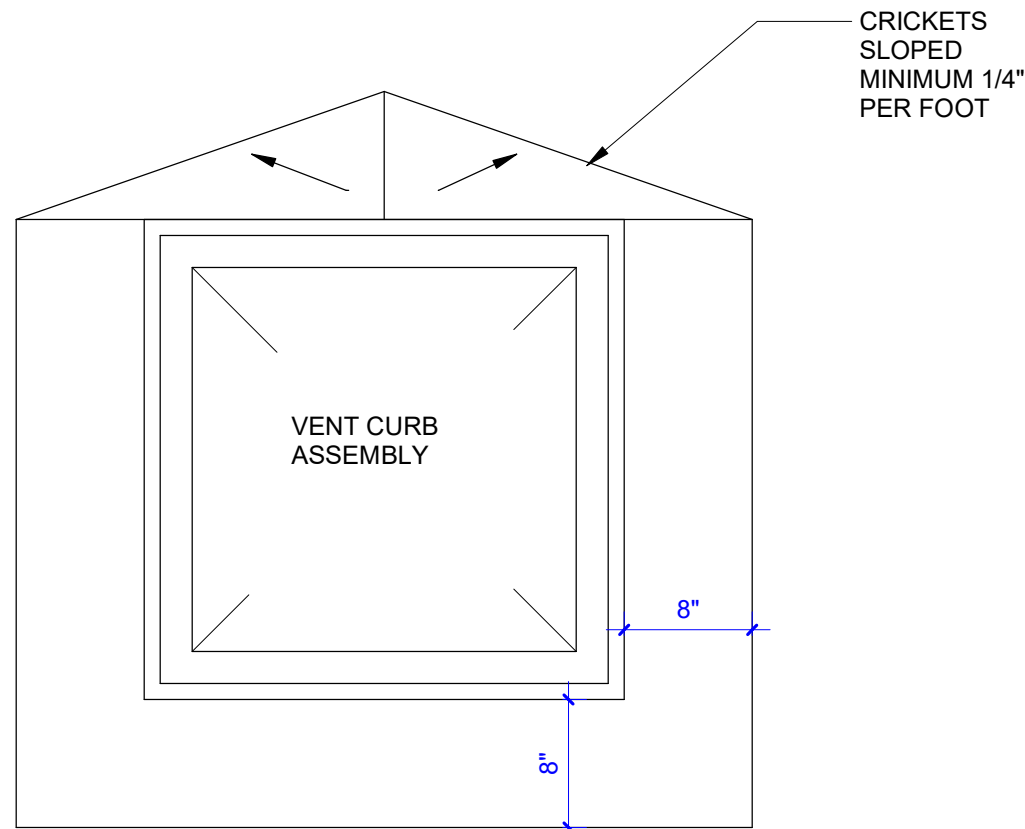


17 CRICKETS
1" = 1'-0"

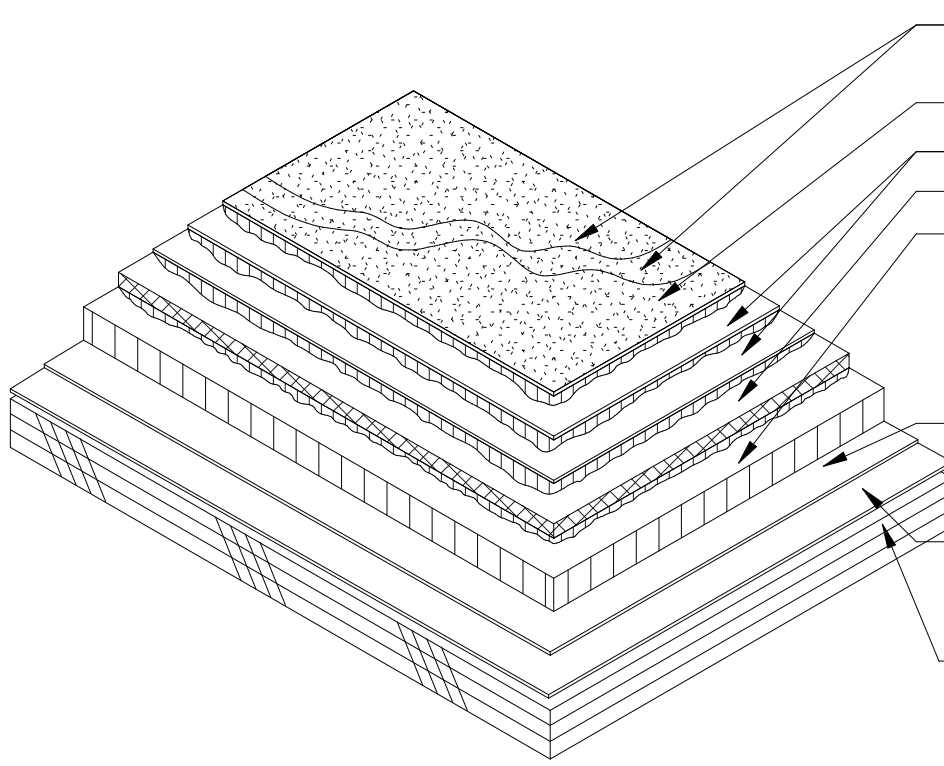


12 TYPICAL B.U.R. SECTION
3" = 1'-0"

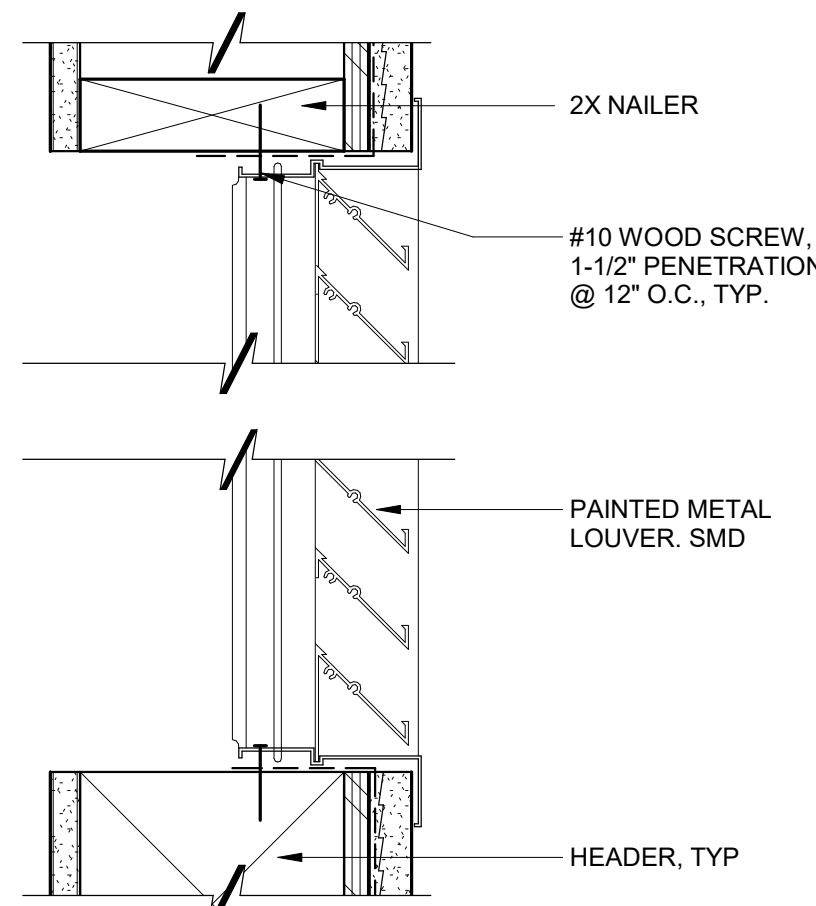


7 EXT. WALL LOUVER
3" = 1'-0"

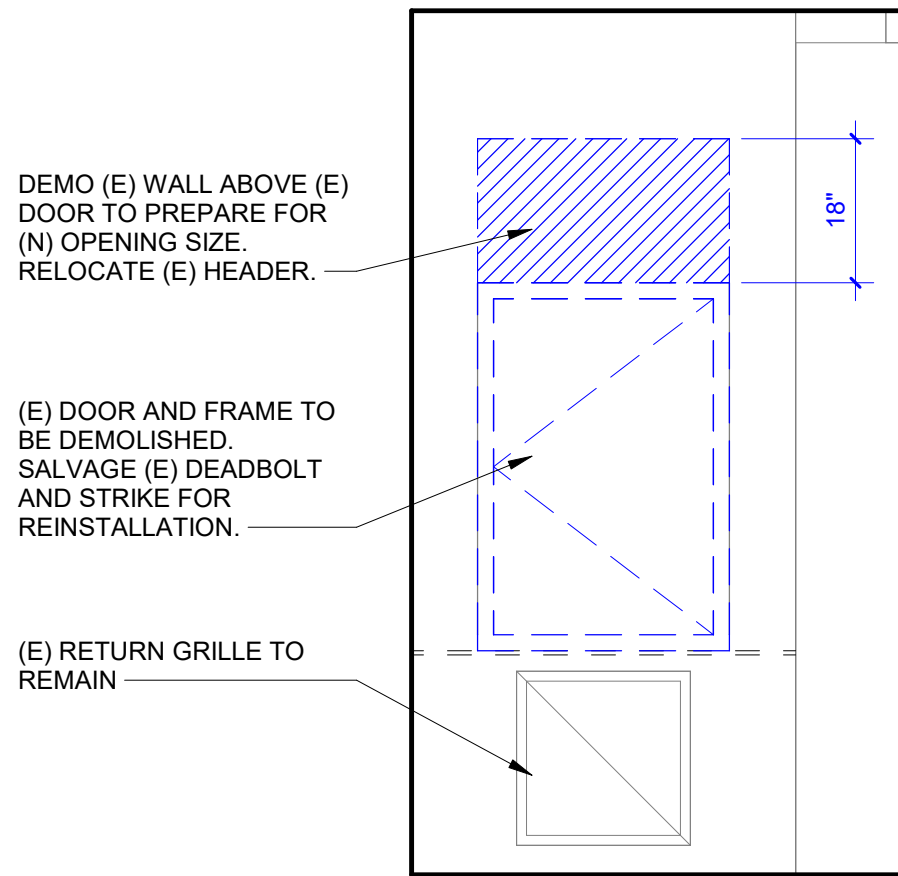


2 TYP. CLASSROOM INTERIOR DOOR DEMO
1/2" = 1'-0"

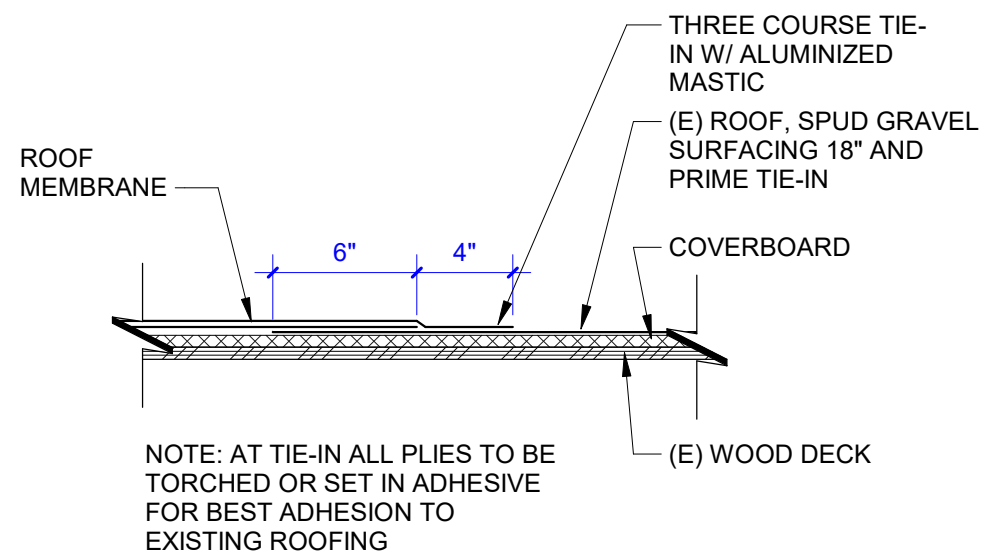


18 ASPHALT ROOF TIE-IN
1 1/2" = 1'-0"

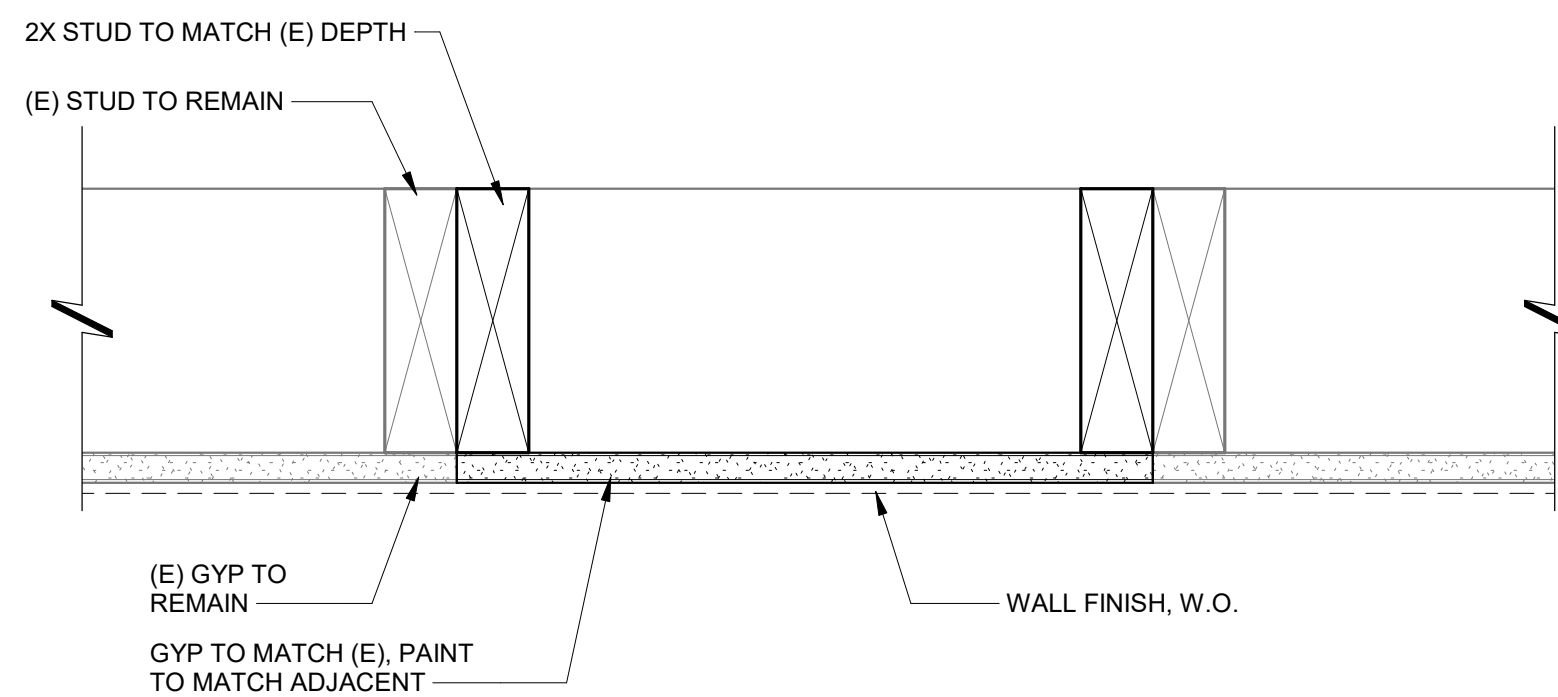


13 INTERIOR WALL SECTION
3" = 1'-0"

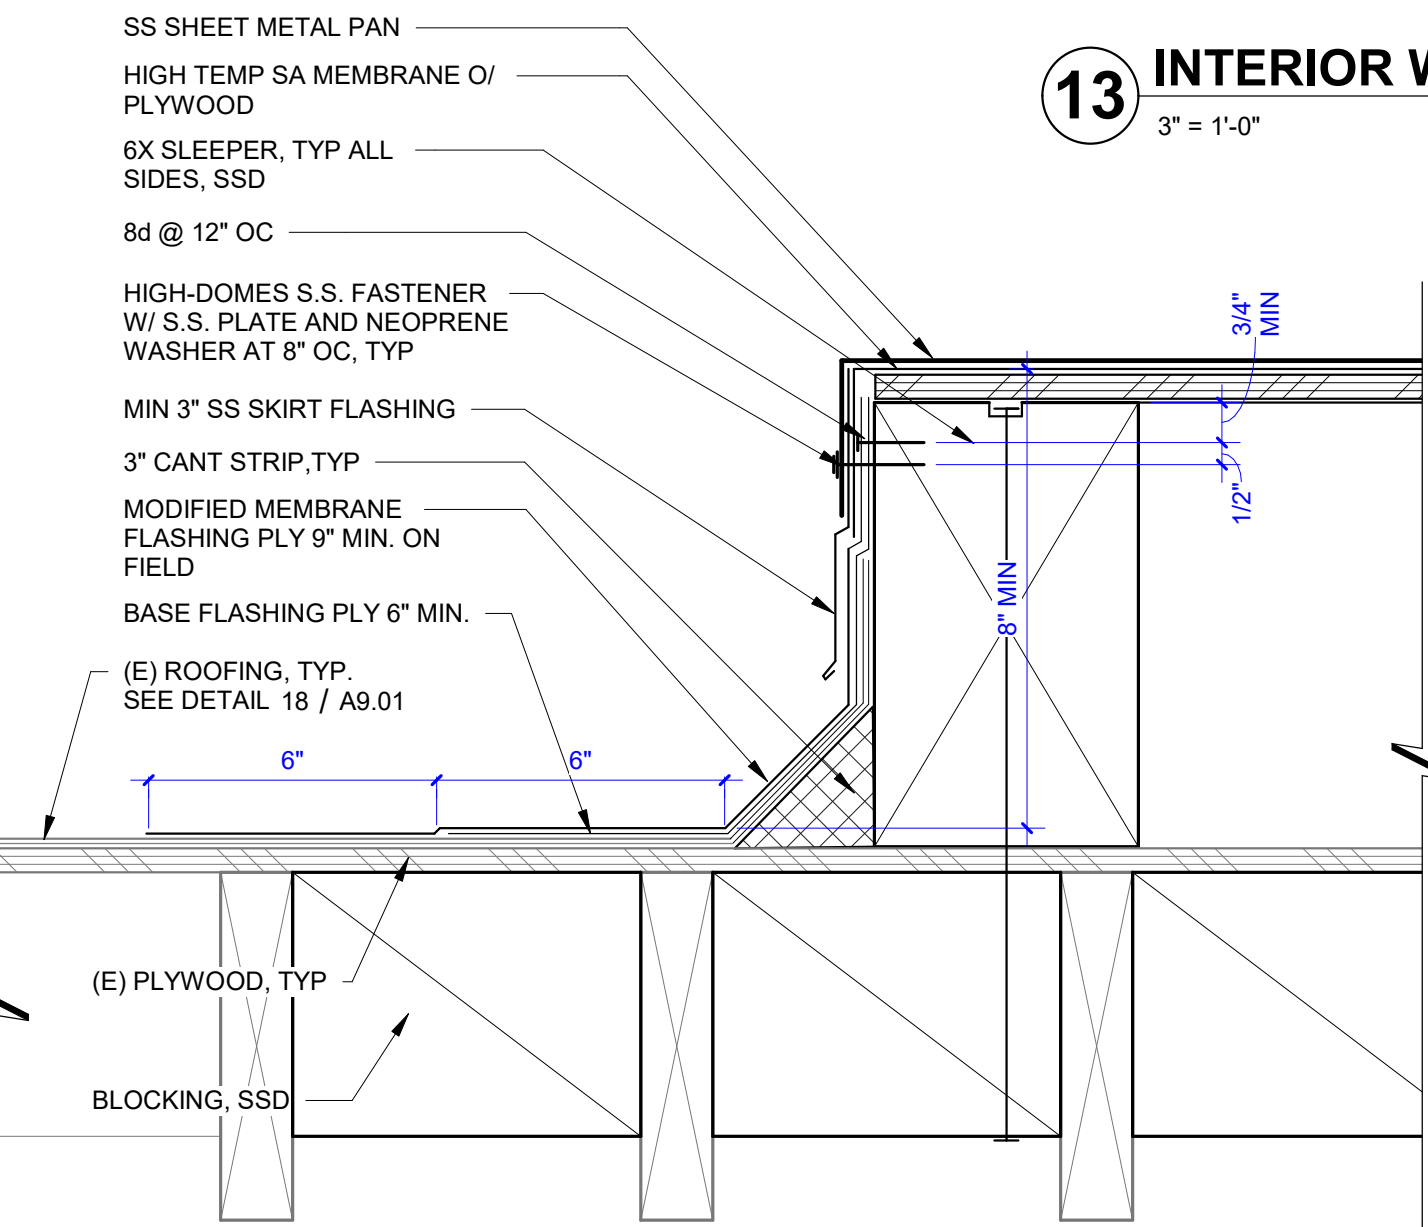


19 ROOFTOP UNIT MOUNTING
3" = 1'-0"

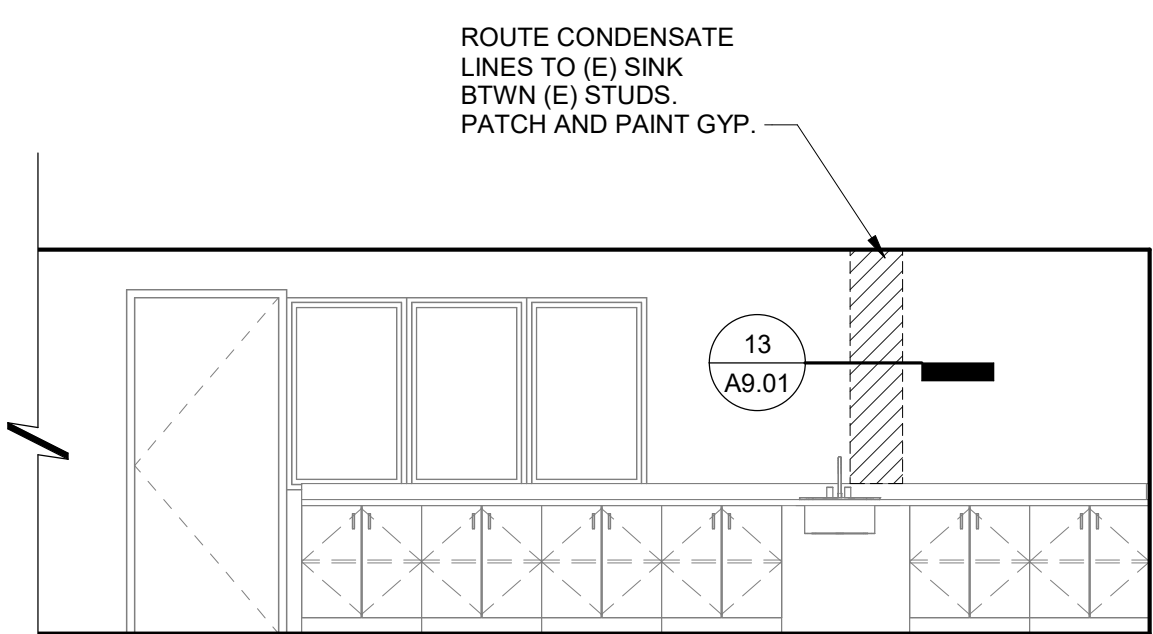


20 INTERIOR ELEVATION - TYPICAL CLASSROOM
1/4" = 1'-0"

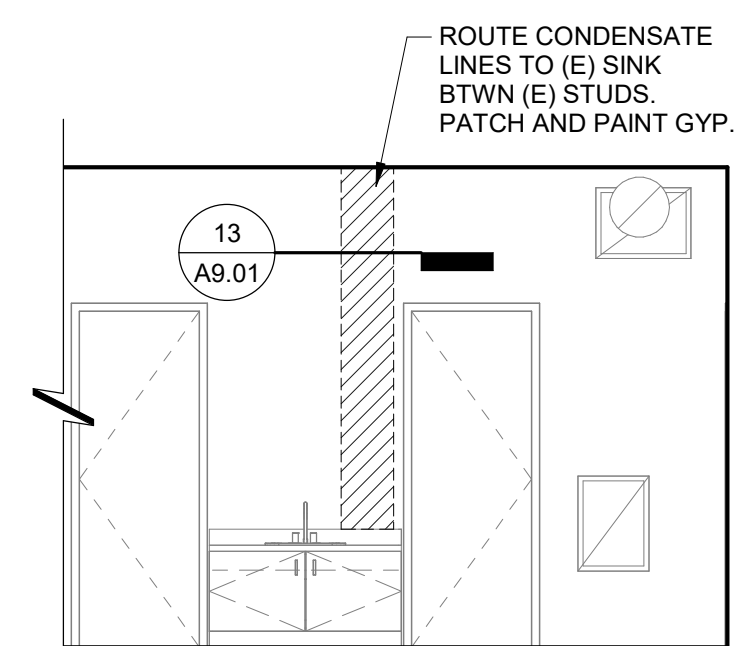


15 INTERIOR ELEVATION - BLDG B
1/4" = 1'-0"

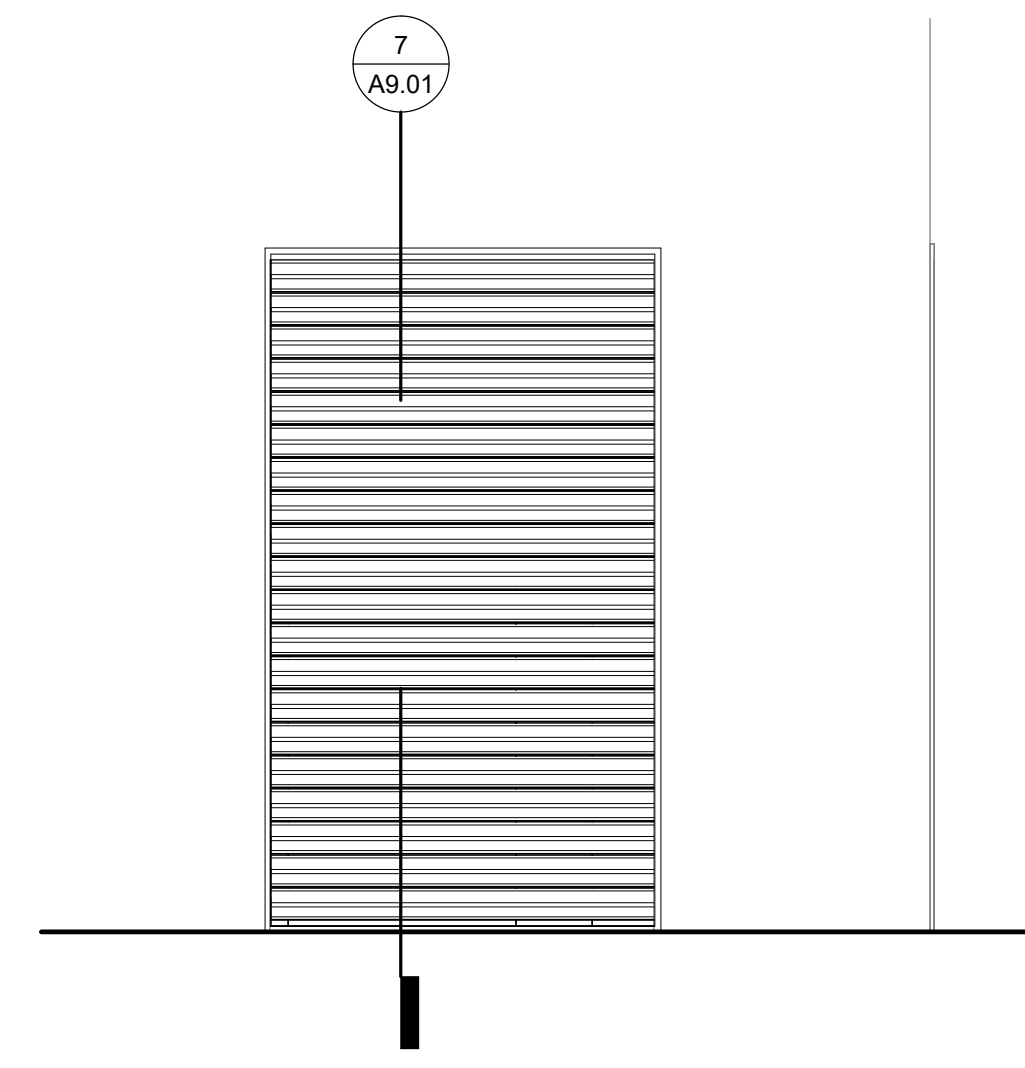


9 ELEVATION - MPR EXTERIOR WALL
1/2" = 1'-0"

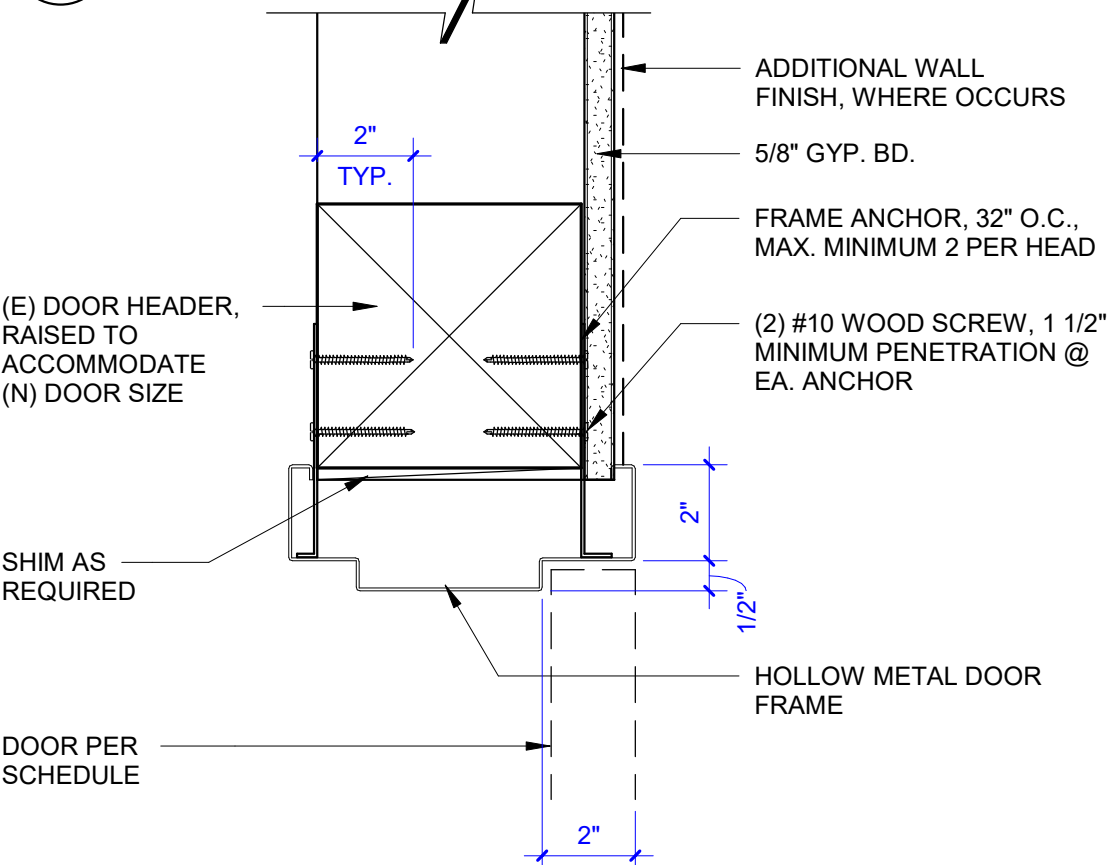


10 INTERIOR DOOR HEAD - WOOD
3" = 1'-0"

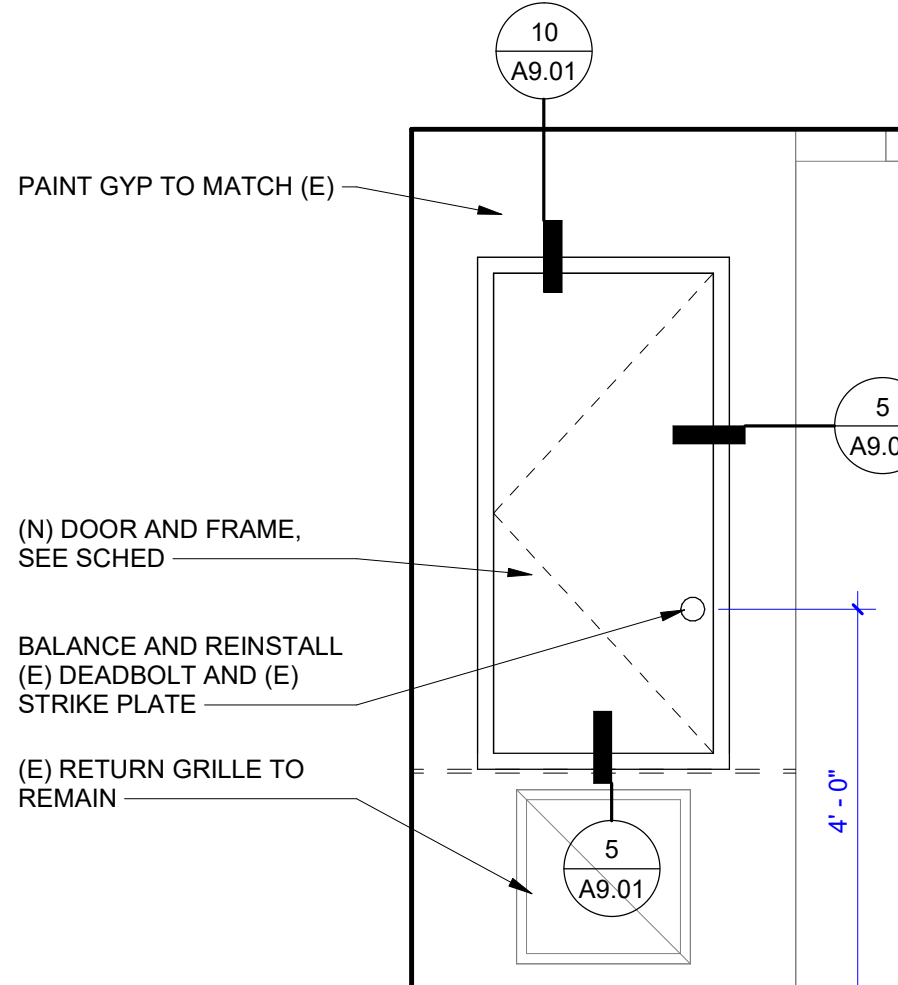

3 TYP. CLASSROOM INTERIOR DOOR
1/2" = 1'-0"

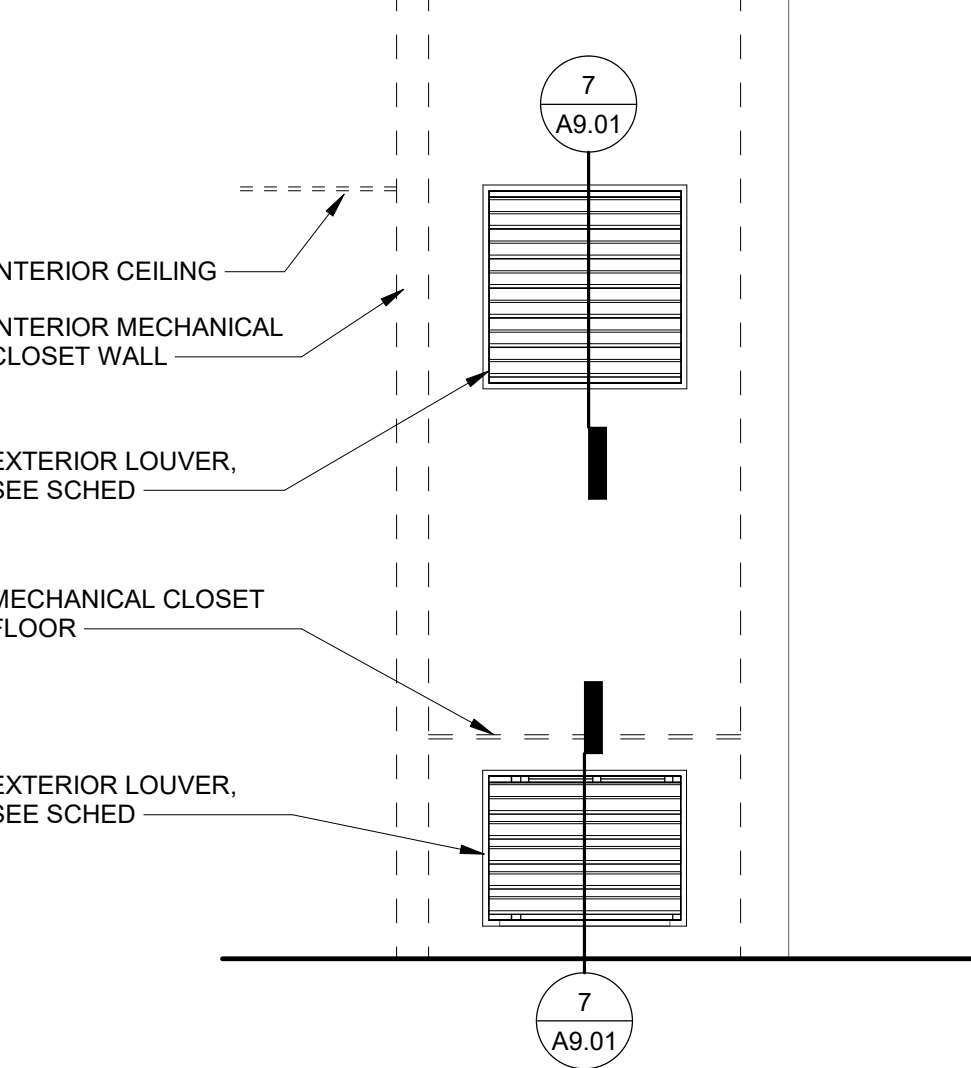

4 TYP. CLASSROOM EXTERIOR LOUVERS
1/2" = 1'-0"

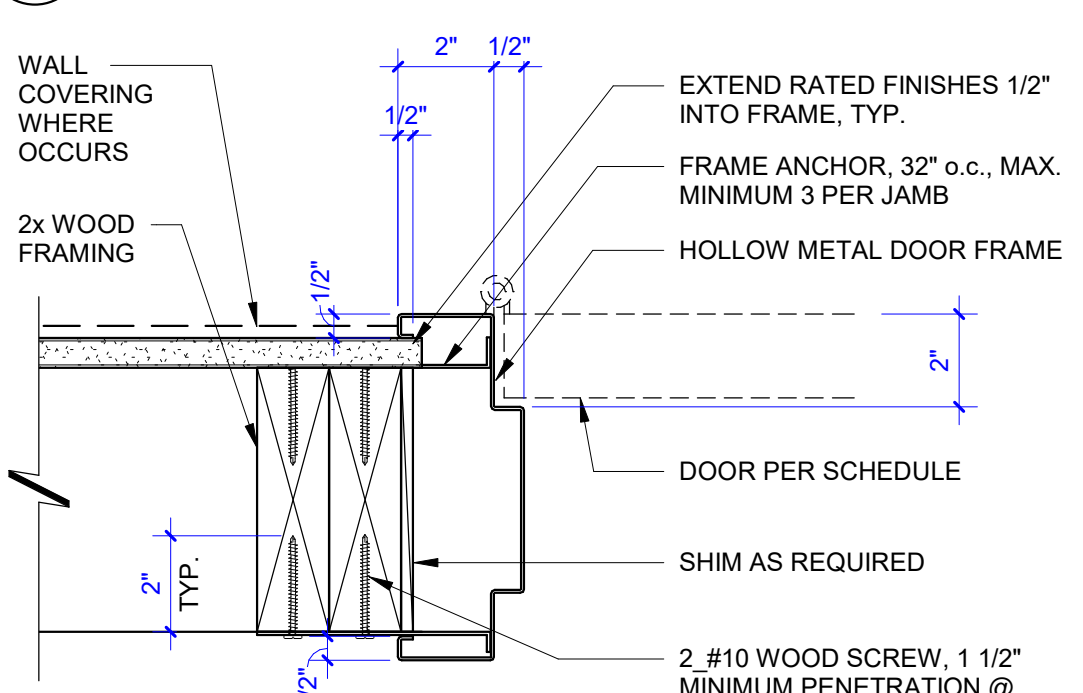

5 INTERIOR HM DOOR JAMB - WOOD (SILL SIMILAR)
3" = 1'-0"

This document is the property of the Owner and is not to be used without their written permission.



HIBSER YAMAUCHI Architects, Inc.
300 - 27th Street
Oakland, CA 94612
510.446.2222 | 510.446.2211 fax

HY Architects Project number: Project Number

Facility
SKYLINE ELEMENTARY SCHOOL
55 CHRISTEN AVE, DALY CITY, CA 94015

Project
HVAC REPLACEMENT

Sheet Title
DETAILS

Client Project Number: 0000.0

Scale: As indicated

Drawn By: Author

Checked By: Checker

Issue Date: Issue Date

Revit Version: 2023

A9.01

Sheet of 200

Z:\Shared\Projects\2024\24259 - Skyline Elementary School HVAC Upgrade\Structural Drawings\24259 - Skyline Elementary School HVAC Upgrade - R23.rvt 2/12/2025 9:28:25 AM



IDENTIFICATION STAMP
DIV. OF THE STATE ARCHITECT
APP: 01-122566 INC.
REVIEWED FOR
SS ☒ FLS ☒ ACS ☐
DATE: 3/10/2026




Revisions	Delta	Date	Revisions	By

SHEET NOTES:

- SEE GENERAL NOTES ON SHEET S1.01.
- FOR TYPICAL WOOD FRAMING DETAILS SEE SHEET S8.01.
- NO WALL OPENINGS ARE PERMITTED WITHOUT SEOR APPROVAL EXCEPT RE-USING EXISTING OPENINGS AND MODIFICATION TO EXISTING OPENINGS AS NOTED ON THESE PLANS AND DETAILS ON SHEET S8.01.

KEY PLAN

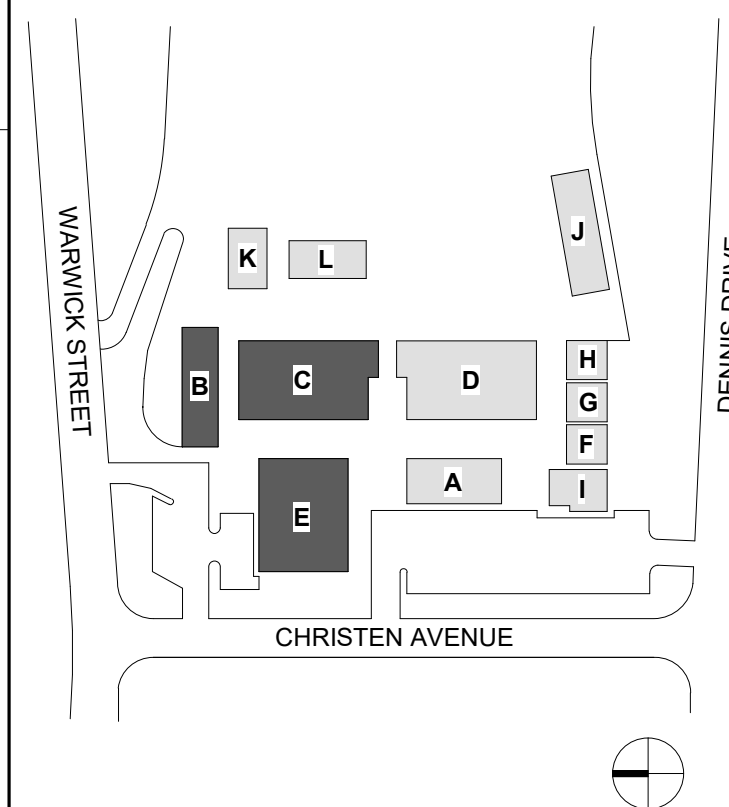

Copyright © 2025 BASE Design
This document is the property of BASE Design
and is not to be used without written permission

**BASE
DESIGN**

582 MARKET ST. STE. 1402
SAN FRANCISCO, CA 94104
Office: (415) 466-2997
www.BASEdesigninc.com

This document is the property of the Owner and is not to be used without their written permission



HY HIBSER YAMAUCHI
Architects, Inc.

300 - 27th Street
Oakland, CA 94612
510.446.2222 tel; 510.446.2211 fax

HY Architects Project number:

Facility
SKYLINE ELEMENTARY SCHOOL
55 CHRISTEN AVE, DALY CITY, CA 94015

Project
HVAC REPLACEMENT

Sheet Title
**ROOF FRAMING PLAN -
BLDGS B, C, AND E**

Client Project Number:



Scale: 1/8" = 1'-0"
Drawn By: SN
Checked By: KMB/JUL
Issue Date: 11/24/2025
Revit Version: 2023

Sheet
of

S2.01

1 ROOF FRAMING PLAN - BLDGS B, C, AND E

1/8" = 1'-0"

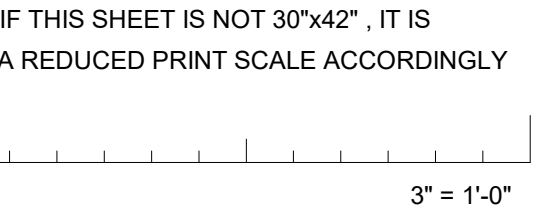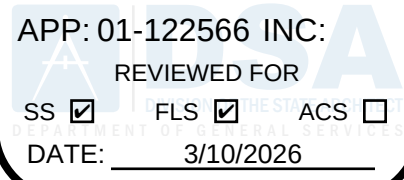


Revisions			
Delta	Date	Revisions	By

SHEET NOTES:

1. SEE GENERAL NOTES ON SHEET S1.01.
2. FOR TYPICAL WOOD FRAMING DETAILS SEE SHEET S8.01.
3. NO WALL OPENINGS ARE PERMITTED WITHOUT SEOR APPROVAL EXCEPT RE-USING EXISTING OPENINGS AND MODIFICATION TO EXISTING OPENINGS AS NOTED ON THESE PLANS AND DETAILS ON SHEET S8.01.

KEY PLAN

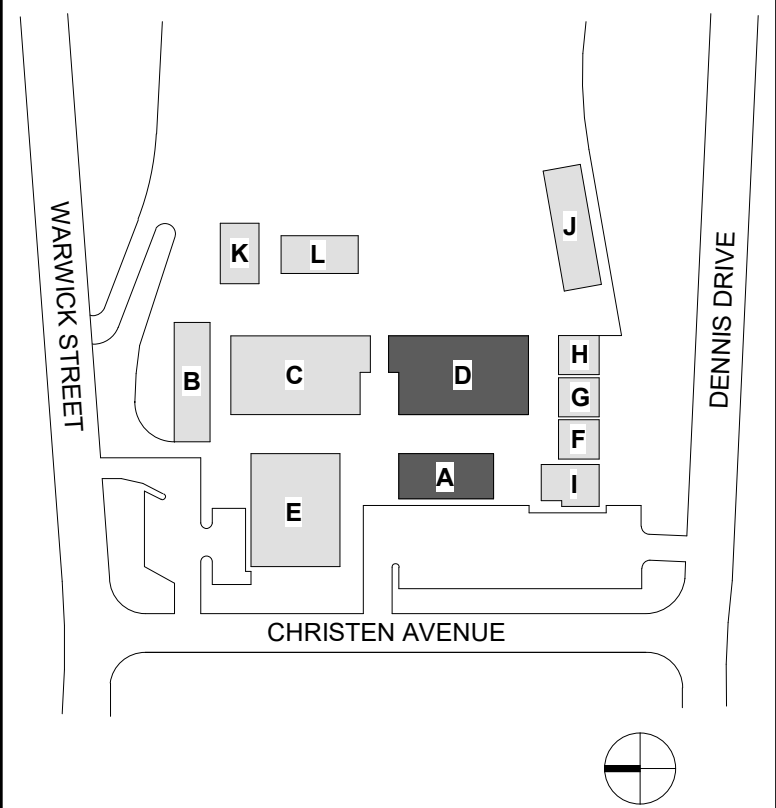

Copyright © 2025 BASE Design
This document is the property of BASE Design
and is not to be used without written permission

**BASE
DESIGN**

582 MARKET ST. STE. 1402
SAN FRANCISCO, CA 94104
Office: (415) 466-2997
www.BASEdesignninc.com



HY HIBSER YAMAUCHI
Architects, Inc.

300 – 27th Street
Oakland, CA 94612
510.446.2222 tel | 510.446.2211 fax

HY Architects Project number:	
Facility	<p>SKYLINE ELEMENTARY SCHOOL 55 CHRISTEN AVE, DALY CITY, CA 94015</p>


Project

HVAC REPLACEMENT

Sheet Title

ROOF FRAMING PLAN -
BLDGS A AND D

Client Project Number:	
Scale: 1/8" = 1'-0"	Sheet
Drawn By: SN	S2.02
Checked By: KMB/JL	
Issue Date: 11/24/2025	
Revit Version: 2023	
	Sheet of

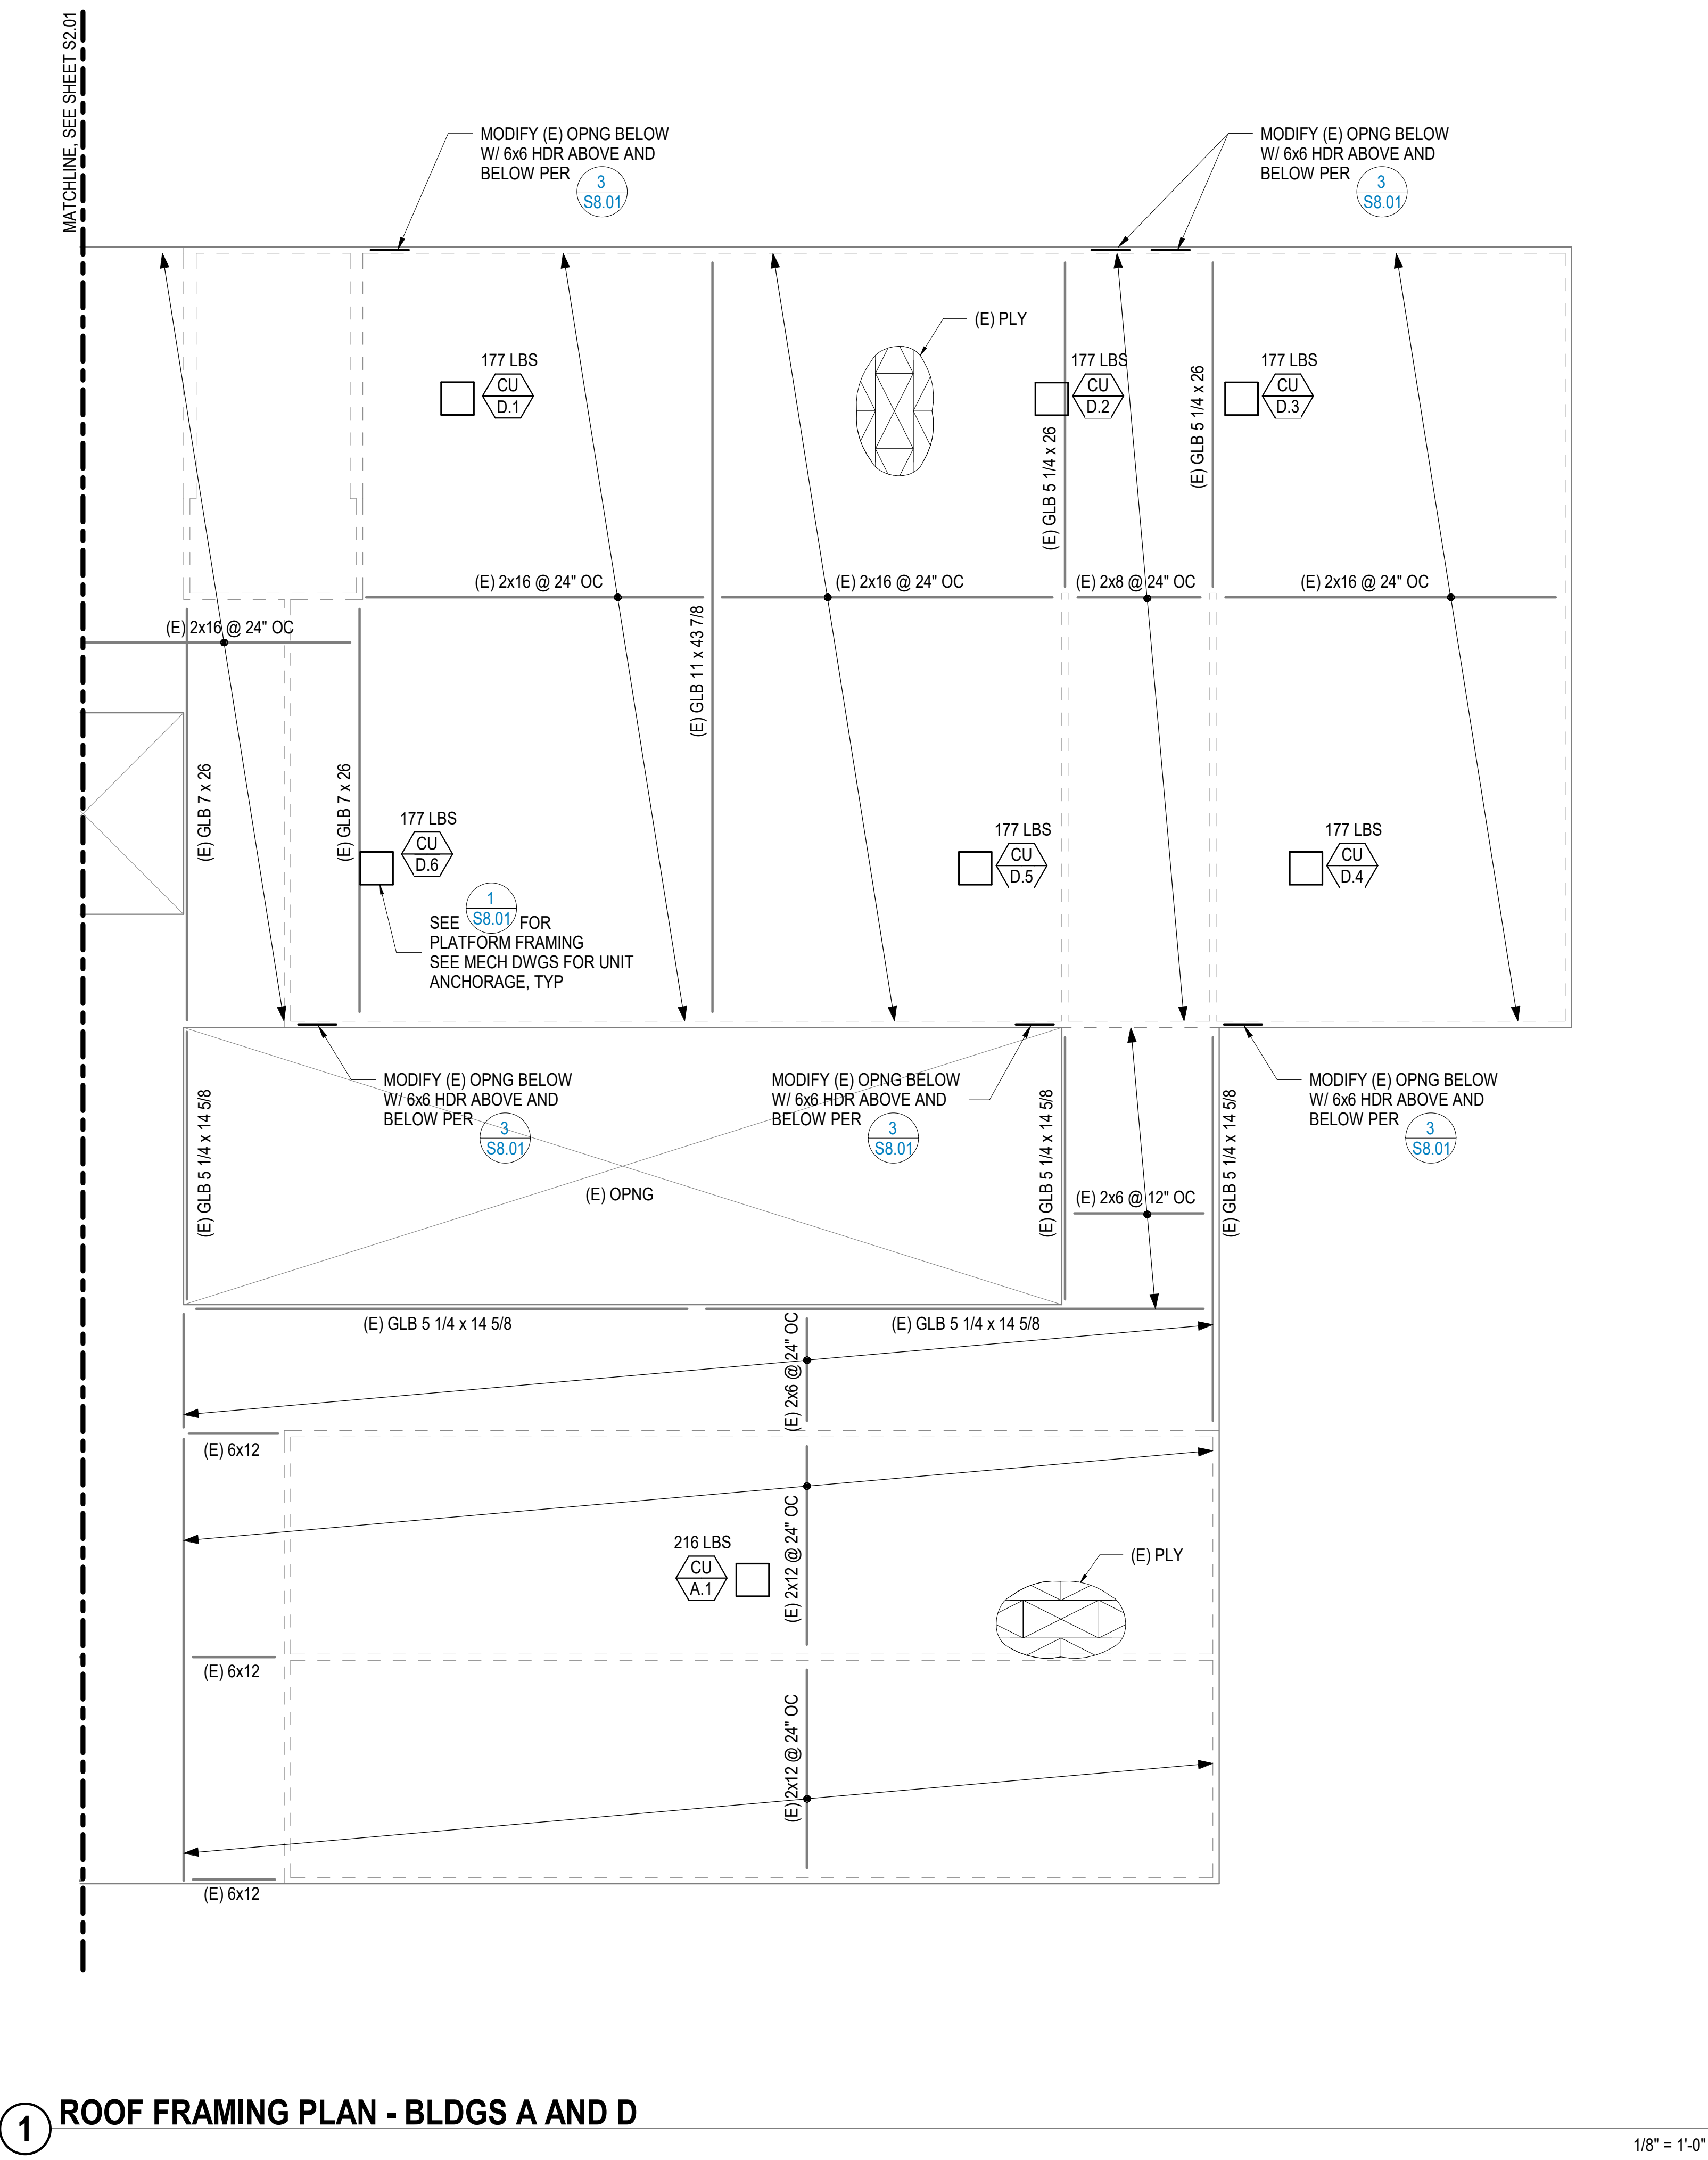

2/12/2026 9:28:25 AM Z:\SharedProjects\2024\242599 - Skyline Elementary School HVAC Upgrade\Structural Drawings\242599 - Skyline Elementary School HVAC Upgrade - R23.rvt




FASTENING SCHEDULE		
DESCRIPTION OF BUILDING ELEMENTS	NUMBER AND TYPE OF FASTENER	SPACING AND LOCATION
ROOF		
1. Blocking between ceiling joists, rafters or trusses to top plate or other framing below	3-8d common (2 1/2" x 0.131"); or 3-10d box (3" x 0.128"); or 3-3" x 0.131" nails; or 3-3" 14 gage staples, 7/16" crown	Each end, toenail
Blocking between rafters or truss not at the wall top plate, to rafter or truss	2-8d common (2 1/2" x 0.131") 2-3" x 0.131" nails 2-3" 14 gage staples	Each end, toenail
	2-16 d common (3 1/2" x 0.162") 3-3" x 0.131" nails 3-3" 14 gage staples	End nail
Flat blocking to truss and web filler	16d common (3 1/2" x 0.162") @ 6" o.c. 3" x 0.131" nails @ 6" o.c. 3" x 14 gage staples @ 6" o.c	Face nail
2. Ceiling joists to top plate	3-8d common (2 1/2" x 0.131"); or 3-10d box (3" x 0.128"); or 3-3" x 0.131" nails; or 3-3" 14 gage staples, 7/16" crown	Each joist, toenail
3. Ceiling joist not attached to parallel rafter, laps over partitions (no thrust)	3-16d common (3 1/2" x 0.163") 4-10d box (3" x 0.128"); or 4-3" x 0.131" nails; or 4-3" 14 gage staples, 7/16" crown	Face nail
4. Ceiling joist attached to parallel rafter (heel joint) (see Section 2308.7.3.1, Table 2308.7.3.1)	Per Table 2308.7.3.1	Face nail
5. Collar tie to rafter	3-10d common (3" x 0.148"); or 4-10d box (3" x 0.128"); or 4-3" x 0.131" nails; or 4-3" 14 gage staples, 7/16" crown	Face nail
6. Rafter or roof truss to top plate	3-10 common (3" x 0.148"); or 3-16d box (3 1/2" x 0.135"); or 4-10d box (3" x 0.128"); or 4-3" x 0.131" nails; or 4-3" 14 gage staples, 7/16" crown	Toenail
7. Roof rafters to ridge valley or hip rafters; or roof rafter to 2-inch ridge beam	2-16d common (3 1/2" x 0.162"); or 3-10d box (3" x 0.128"); or 3-3" x 0.131" nails; or 3-3" 14 gage staples, 7/16" crown; or 3-10d common (3 1/2" x 0.148"); or 4-16d box (3 1/2" x 0.135"); or 4-10d box (3" x 0.128"); or 4-3" x 0.131" nails; or 4-3" 14 gage staples, 7/16" crown	End nail Toenail
WALL		
8. Stud to stud (not at braced wall panels)	16d common (3 1/2" x 0.162"); 10d box (3" x 0.128"); or 3" x 0.131" nails; or 3-3" 14 gage staples, 7/16" crown	24" o.c. face nail 16" o.c. face nail
9. Stud to stud and abutting studs at intersecting wall corners (at braced wall panels)	16d common (3 1/2" x 0.162"); or 16d box (3 1/2" x 0.135"); or 3" x 0.131" nails; or 3-3" 14 gage staples, 7/16" crown	16" o.c. face nail 12" o.c. face nail 12" o.c. face nail
10. Built-up header (2" to 2" header)	16d common (3 1/2" x 0.162"); or 16d box (3 1/2" x 0.135")	16" o.c. each edge, face nail 16" o.c. each edge, face nail
11. Continuous header to stud	4-8d common (2 1/2" x 0.131"); or 4-10d box (3" x 0.128")	Toenail
12. Top plate to top plate	16d common (3 1/2" x 0.162"); or 10d box (3" x 0.128"); or 3" x 0.131" nails; or 3" 14 gage staples, 7/16" crown	16" o.c. face nail 12" o.c. face nail
13. Top plate to top plate, at end joints	8-16d common (3 1/2" x 0.162"); or 12-10d box (3" x 0.128"); or 12-3" x 0.131" nails; or 12-3" 14 gage staples, 7/16" crown	Each side of end joint, face nail (minimum 24" lap splice length each side of end joint)
14. Bottom plate to joist, rim joist, band joist or blocking (not at braced wall panels)	16d common (3 1/2"x0.163"); or 16d box (3 1/2" x 0.135"); or 3" x 0.131" nails; or 3" 14 gage staples, 7/16" crown	16" o.c. face nail 12" o.c. face nail
15. Bottom plate to joist, rim joist, band joist or blocking at braced wall panels	2-16d common (3 1/2" x 0.162"); or 3-16d box (3 1/2" x 0.135"); or 4-3" x 0.131" nails; or 4-3" 14 gage staples, 7/16" crown	16" o.c. face nail
16. Stud to top or bottom plate	4-8d common (2 1/2" x 0.131"); or 4-10d box (3" x 0.128"); or 4-3" x 0.131" nails; or 4-3" 14 gage staples, 7/16" crown; or 2-16d common (3 1/2" x 0.162"); or 3-10d box (3" x 0.128"); or 3-3" x 0.131" nails; or 3-3" 14 gage staples, 7/16" crown	Toenail End nail
17. Top plates, laps at corners and intersections	2-16d common (3 1/2" x 0.162"); or 3-10d box (3" x 0.128"); or 3-3" x 0.131" nails; or 3-3" 14 gage staples, 7/16" crown	Face nail
18. 1" brace to each stud and plate	2-8d common (2 1/2" x 0.131"); or 2-10d box (3" x 0.128"); or 2-3" x 0.131" nails; or 2-3" 14 gage staples, 7/16" crown	Face nail
19. 1" x 6" sheathing to each bearing	2-8d common (2 1/2" x 0.131"); or 2-10d box (3" x 0.128")	Face nail
20. 1" x 8" and wider sheathing to each bearing	3-8d common (2 1/2" x 0.131"); or 3-10d box (3" x 0.128")	Face nail

FASTENING SCHEDULE (CONT.)			
DESCRIPTION OF BUILDING ELEMENTS	NUMBER AND TYPE OF FASTENER	SPACING AND LOCATION	
FLOOR			
21. Joist to sill, top plate, or girder	3-8d common (2 1/2" × 0.131"); or floor 3-10d box (3" × 0.128"); or 3-3" × 0.131" nails; or 3-3" 14 gage staples, 7/16" crown	Toenail	
22. Rim joist, band joist, or blocking to top plate, sill or other framing below	8d common (2 1/2" × 0.131"); or floor 10d box (3" × 0.128"); or 3" × 0.131" nails; or 3" 14 gage staples, 7/16" crown	6" o.c., toenail	
23. 1" × 6" subfloor or less to each joist	2-8d common (2 1/2" × 0.131"); or 2-10d box (3" × 0.128")	Face nail	
24. 2" subfloor to joist or girder	2-16d common (3 1/2" × 0.162")	Face nail	
25. 2" planks (plank & beam – floor & roof)	2-16d common (3 1/2" × 0.162")	Each bearing, face nail	
26. Built-up girders and beams, 2" lumber layers	20d common (4" × 0.192")	32" o.c., face nail at top and bottom staggered on opposite sides	
	10d box (3" × 0.128"); or 3" × 0.131" nails; or 3" 14 gage staples, 7/16" crown	24" o.c. face nail at top and bottom staggered on opposite sides	
	And: 2-20d common (4" × 0.192"); or 3-10d box (3" × 0.128"); or 3-3" × 0.131" nails; or 3-3" 14 gage staples, 7/16" crown	Ends and at each splice, face nail	
27. Ledger strip supporting joists or rafters	3-16d common (3 1/2" × 0.162"); or 4-10d box (3" × 0.128"); or 4-3" × 0.131" nails; or 4-3" 14 gage staples, 7/16" crown	Each joist or rafter, face nail	
28. Joist to band joist or rim joist	3-16d common (3 1/2" × 0.162"); or 4-10d box (3" × 0.128"); or 4-3" × 0.131" nails; or 4-3" 14 gage staples, 7/16" crown	End nail	
29. Bridging or blocking to joist, rafter or truss	2-8d common (2 1/2" × 0.131"); or 2-10d box (3" × 0.128"); or 2-3" × 0.131" nails; or 2-3" 14 gage staples, 7/16" crown	Each end, toenail	
Wood structural panels (WSP), subfloor, roof and interior wall sheathing to framing and particleboard wall sheathing to framing			
		Edges (inches)	Intermediate supports (inches)
30. 3/8" – 1/2"	6d common or deformed (2" × 0.113"); or 2 3/8" × 0.113 nails (subfloor and wall)	6	
	8d common or deformed (2 1/2" × 0.113" x 0.281" head) (roof) or RSRS-01 (2 3/8" x 0.133") nail (roof)	6	
	1 3/4" 16 gage staple, 7/16" crown (subfloor and wall)	4	
	2 3/8" × 0.113" x 0.266 head nail (roof)	3	
31. 19/32" – 3/4"	1 3/4" 16 gage staple, 7/16" crown (roof)	3	
	8d common (2 1/2" × 0.131"); or deformed (2" × 0.113") (subfloor and wall)	6	
	8d common or deformed (2 1/2" × 0.131" x 0.281" head) (roof) or RSRS-01 (2 3/8" x 0.113") nail (roof)	6	
	2 3/8" × 0.113" x 0.266" head nail; or 2" 16 gage staple, 7/16" crown	4	
32. 7/8" – 1 1/4"	10d common (3" × 0.148"); or deformed (2 1/2" × 0.131" x 0.281" head)	6	
Other exterior wall sheathing			
33. 1/2" fiberboard sheathingb	1 1/2" galvanized roofing nail (7/16" head diameter); or 1 1/4" 16 gage staple with 7/16" or 1" crown	3	6
34. 25/32" fiberboard sheathingb	1 3/4" galvanized roofing nail (7/16" diameter head); or 1 1/2" 16 gage staple with 7/16" or 1" crown	3	6
Wood structural panels, combination subfloor underlayment to framing			
35. 3/4" and less	8d common (2 1/2" × 0.131"); or 6d deformed (2" × 0.113")	6	12
36. 7/8" – 1"	8d common (2 1/2" × 0.131"); or 8d deformed (2 1/2" × 0.131")	6	12
37. 1 1/8" – 1 1/4"	10d common (3" × 0.148"); or 8d deformed (2 1/2" × 0.131")	6	12
Panel siding to framing			
38. 1/2" or less	6d corrosion-resistant siding (1 7/8" × 0.106"); or 6d corrosion-resistant casing (2" × 0.099")	6	12
39. 5/8"	8d corrosion-resistant siding (2 3/8" × 0.128"); or 8d corrosion-resistant casing (2 1/2" × 0.113")	6	12
Wood structural panels (WSP), subfloor, roof and interior wall sheathing to framing and particleboard wall sheathing to framing a			
		Edges (inches)	Intermediate supports (inches)
40. 1/4"	4d casing (1 1/2" × 0.080"); or 4d finish (1 1/2" × 0.072")	6	12
41. 3/8"	6d casing (2" × 0.099"); or 6d finish (Panel supports at 24 inches)	6	12

For S1: 1 inch = 25.4 mm.
a. Nails spaced at 6 inches at intermediate supports where spans are 48 inches or more. Nails for wall sheathing are permitted to be common, box or casing.
b. Spacing shall be 8 inches on center on the edges and 12 inches on center at intermediate supports for nonstructural applications. Panel supports at 16 inches (20 inches if strength axis in the long direction of the panel, unless otherwise marked).
c. Where a rafter is fastened to an adjacent parallel ceiling joist in accordance with this schedule and the ceiling joist is fastened to the top plate in accordance with this schedule, the number of toenails in the rafter shall be permitted to be reduced by one nail.
d. RSR5-01 is a Roof Sheathing Ring Shank nail meeting the specifications in ASTM F1667.

12 NAILING SCHEDULE


4 OPENING IN DIAPHRAGM

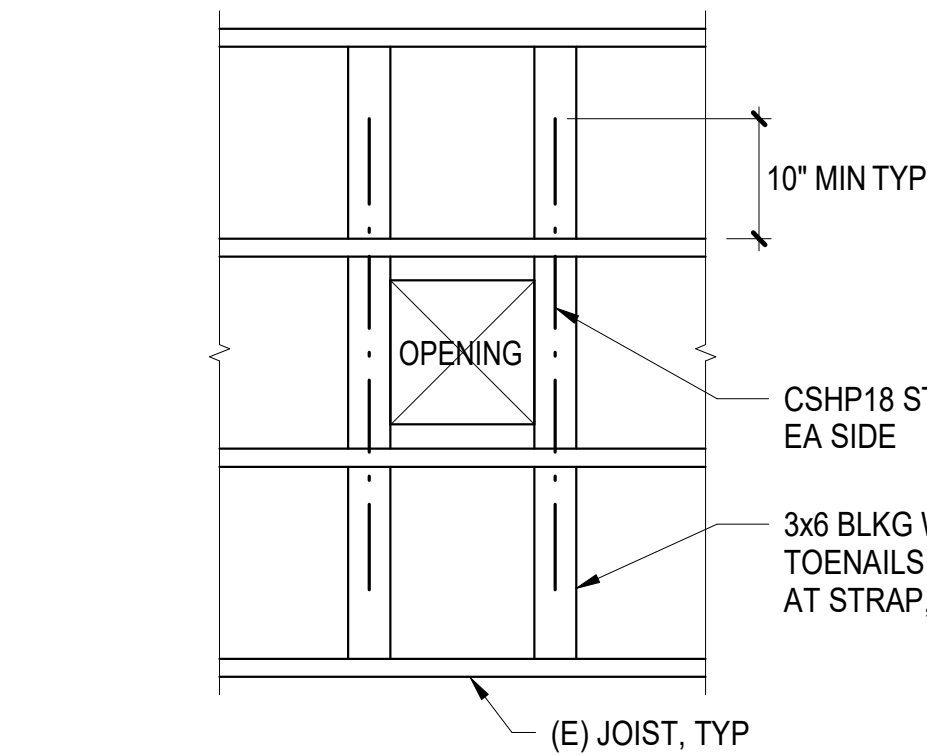

NOTE:
ADJACENT OPENINGS SHALL BE SPACED AT 6' - 0" MINIMUM.


5 SMALL OPENING IN DIAPHRAGM (22"x22" MAX)

1 MECH UNIT PLATFORM DETAIL

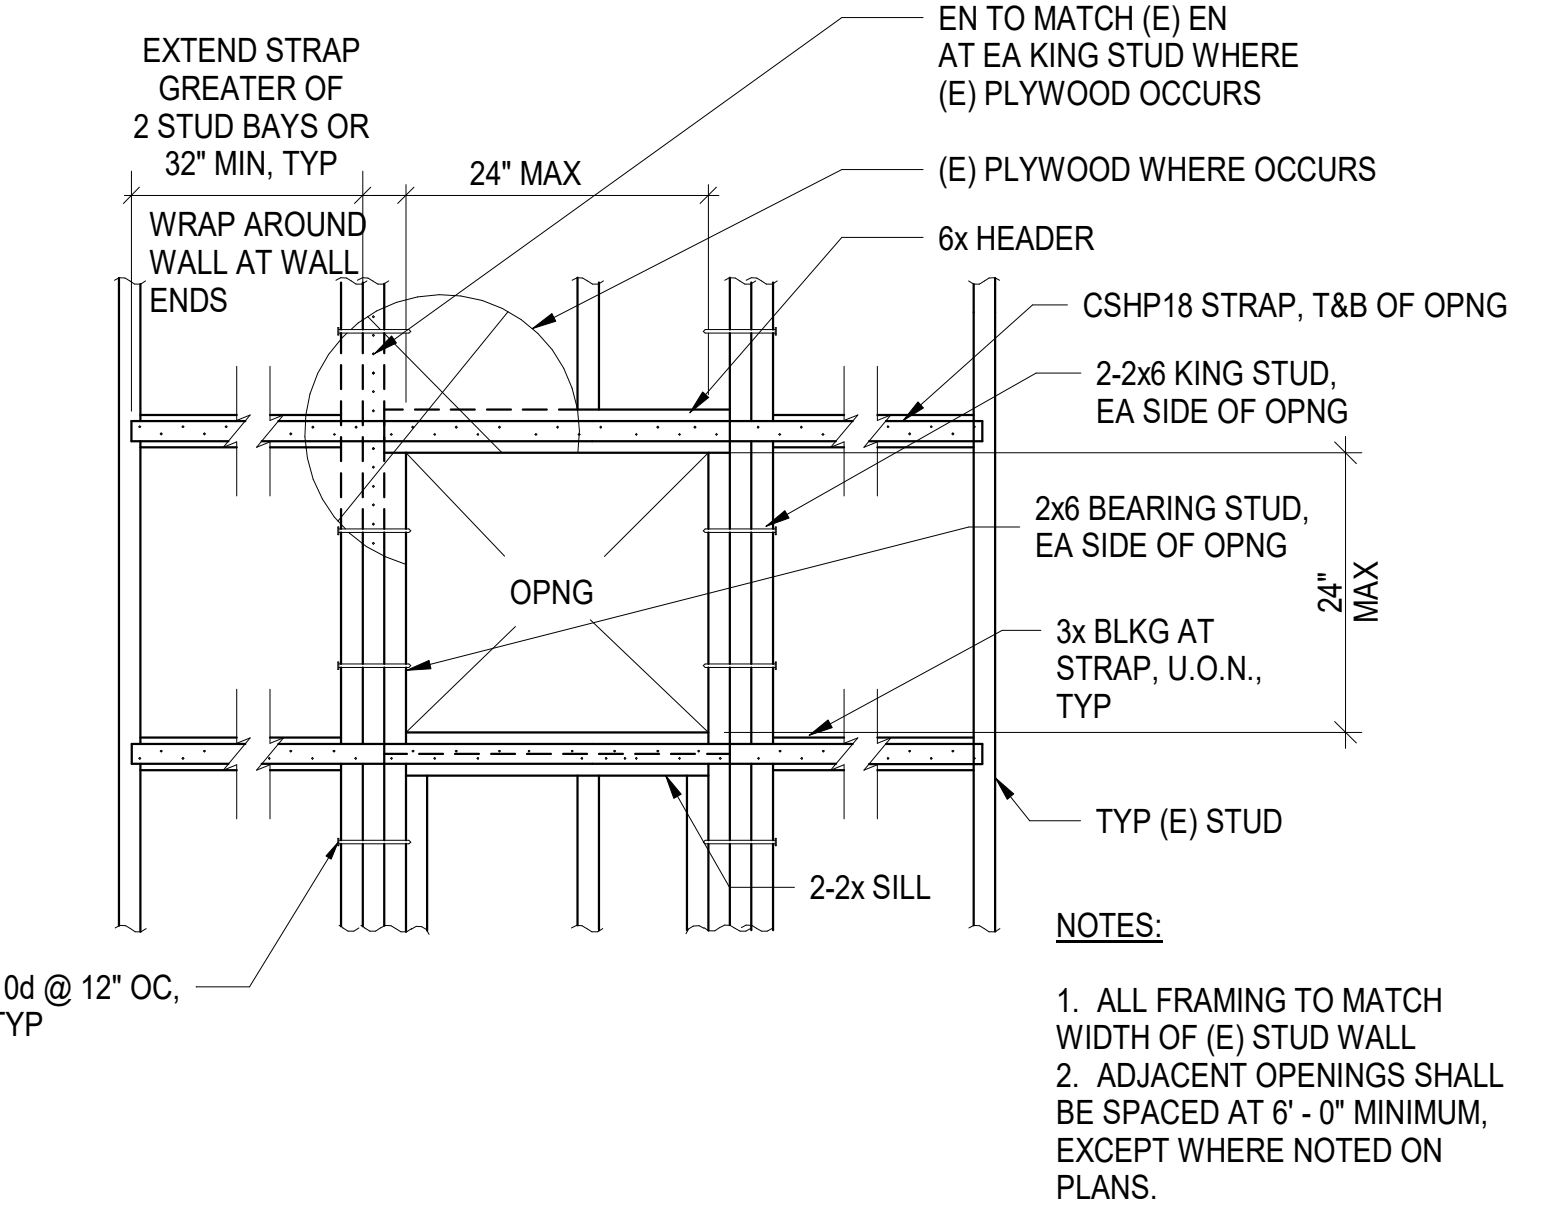


NOTES:
1. ALL FRAMING TO MATCH WIDTH OF (E) STUD WALL
2. ADJACENT OPENINGS SHALL BE SPACED AT 6' - 0" MINIMUM, EXCEPT WHERE NOTED ON PLANS.

2 SMALL OPENING IN WALL

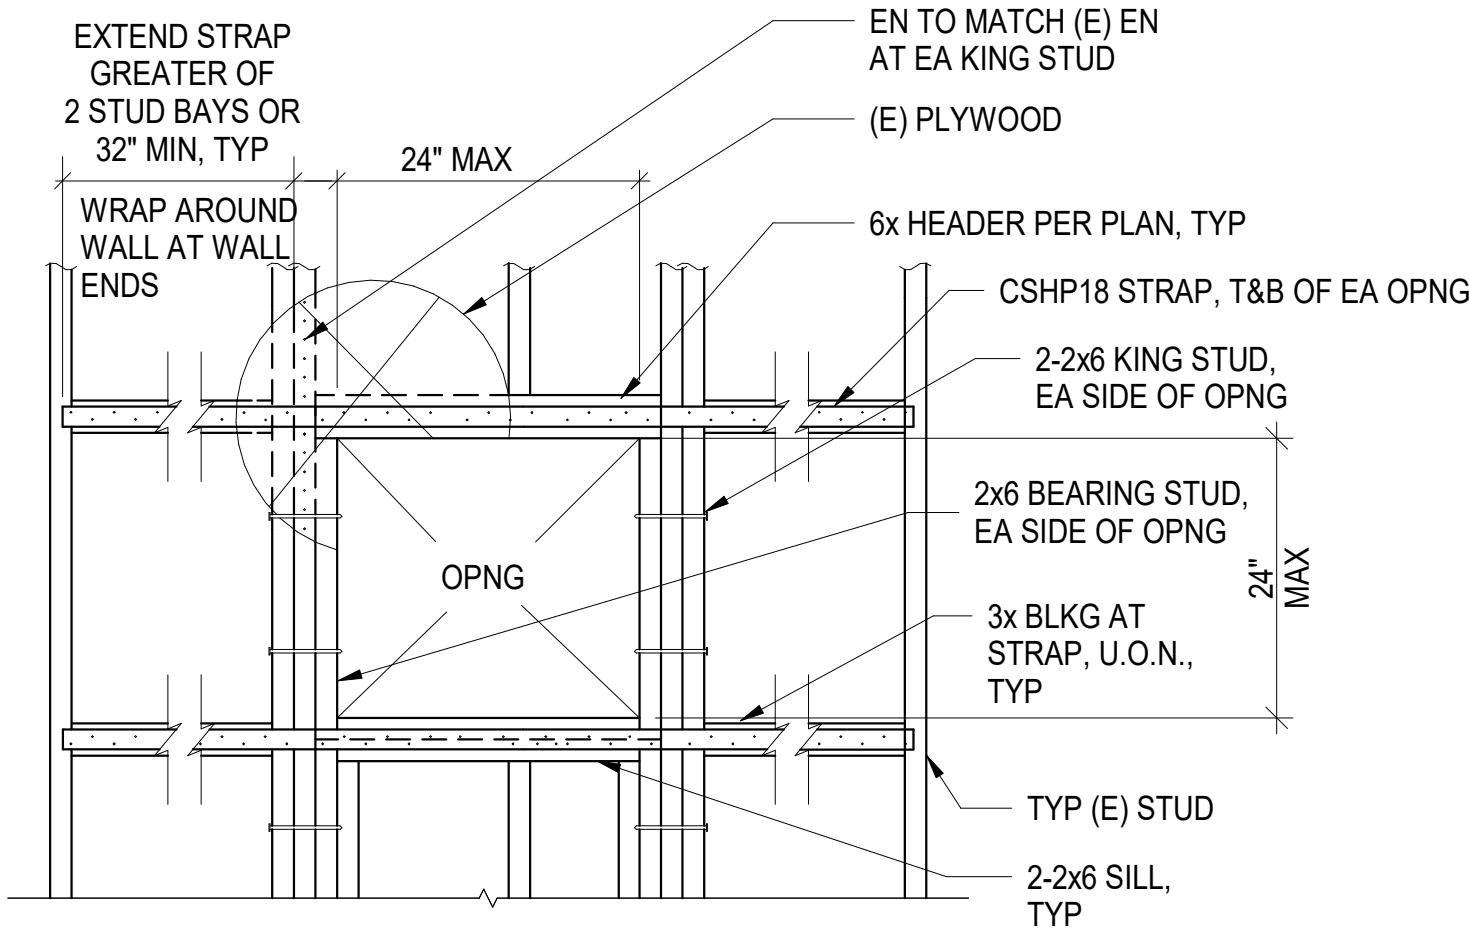

NOTE:
ADJACENT OPENINGS SHALL BE SPACED AT 6' - 0" MINIMUM, EXCEPT WHERE NOTED ON PLANS.

3 STACKED SMALL OPENINGS IN WALL

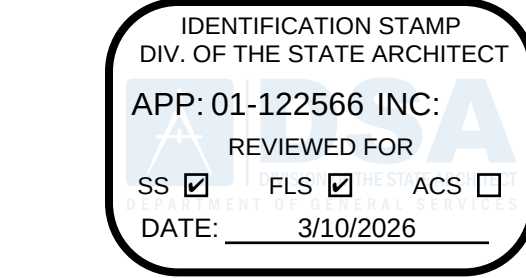

Revisions	Delta	Date	Revisions	By
-----------	-------	------	-----------	----

--	--	--	--	--

--	--	--	--	--

--	--	--	--	--

--	--	--	--	--

--	--	--	--	--

--	--	--	--	--

--	--	--	--	--

--	--	--	--	--

Copyright © 2025 BASE Design
This document is the property of BASE Design and is not to be used without written permission

BASE DESIGN

582 MARKET ST. STE. 1402
SAN FRANCISCO, CA 94104
Office: (415) 466-2997
www.BASEdesigninc.com

This document is the property of the Owner and is not to be used without their written permission



HY

HIBSER YAMAUCHI Architects, Inc.

300 – 27th Street
Oakland, CA 94612
510.446.2222 tel | 510.446.2211 fax

HY Architects Project number:

Facility
SKYLINE ELEMENTARY SCHOOL
55 CHRISTEN AVE, DALY CITY, CA 94015

Project

HVAC REPLACEMENT

Sheet Title

NAILING SCHEDULE AND WOOD DETAILS

Client Project Number:

Scale: As indicated

Drawn By: SN

Checked By: KMB/JL

Issue Date: 11/24/2025

Revit Version: 2023

Sheet

S8.01

Sheet of

3/20/2023 3:12:50 PM M:\P - PROJECTS\20250502-25-0001 SFUSD SKYLINE ES\02 MECH



MECHANICAL GENERAL NOTES

1. ENTIRE INSTALLATION SHALL CONFORM TO REQUIREMENTS OF 2022 CALIFORNIA MECHANICAL CODE, 2022 CALIFORNIA BUILDING CODE, AND ALL OTHER APPLICABLE CODES AND REGULATIONS, INCLUDING 2016 CALIFORNIA ENERGY CONSERVATION STANDARDS DIVISION T-24 & T-20.
2. 2022 CALIFORNIA GREEN BUILDING STANDARDS (CALGREEN) CODE INCLUDING APPLICABLE MANDATORY MEASURES:

a. COVERING OF DUCT OPENINGS AND PROTECTION OF MECHANICAL EQUIPMENT DURING CONSTRUCTION PER CALGREEN REQUIREMENTS.

b. ADHESIVES, SEALANTS AND CAULKS SHALL MEET CALGREEN REQUIREMENTS.

c. FILTERS SHALL BE A MINIMUM EFFICIENCY REPORTING VALUE (MERV) OF 13 OR AS SPECIFIED.

d. INSTALLATIONS OF HVAC AND REFRIGERATION EQUIPMENT SHALL COMPLY WITH SECTIONS 5.508.1.1 AND 5.508.1.2.
3. COORDINATE ENTIRE INSTALLATION OF HVAC SYSTEM WITH WORK OF ALL OTHER TRADES PRIOR TO ANY FABRICATION OR INSTALLATION. PROVIDE ALL FITTINGS, OFFSETS, AND TRANSITIONS AS REQUIRED FOR A COMPLETE WORKABLE INSTALLATION. MECHANICAL CONTRACTOR SHALL BE RESPONSIBLE TO COORDINATE ITEMS TO BE PROVIDED BY OTHER TRADES WHERE MENTIONED IN THE CONTRACT DOCUMENTS PRIOR TO BID - NO EXCEPTIONS.
4. CONTRACTOR SHALL NOTIFY OWNER AND ENGINEER OF CONSTRUCTION PHASING PRIOR TO START OF CONSTRUCTION, REMOVAL, AND/OR REPLACEMENT OF ANY EQUIPMENT. CONTRACTOR SHALL RECEIVE PERMISSION IN WRITING PRIOR TO START OF ANY WORK DURING ANY PHASE FOR WORK SHOWN HEREIN. IT SHALL BE THE RESPONSIBILITY OF CONTRACTOR TO CONDUCT WORK AND ARRANGE HIS WORK IN A MANNER THAT WILL CAUSE MINIMAL INTERFERENCE WITH DAILY FUNCTIONS WITHIN FACILITY. ANY EXPECTED DOWNTIME SHALL BE COORDINATED WITH THE OWNER.
5. ALL EQUIPMENT, DUCTS, PIPING, AND OTHER DEVICES AND MATERIALS INSTALLED OUTSIDE OF BUILDING OR OTHERWISE EXPOSED TO WEATHER SHALL BE COMPLETELY WEATHER-PROOFED AND PAINTED TO MATCH; COORDINATE WITH ARCHITECT PRIOR TO PAINTING.
6. THE OWNER ACKNOWLEDGES THAT DESIGN PROFESSIONAL CONSTRUCTION DOCUMENTS AND SPECIFICATIONS ARE INSTRUMENTS OF PROFESSIONAL SERVICES. NEVERTHELESS, CONSTRUCTION DOCUMENTS AND SPECIFICATIONS PREPARED UNDER THIS AGREEMENT SHALL BECOME THE PROPERTY OF THE OWNER UPON COMPLETION OF THE WORK. THE OWNER AGREES TO HOLD HARMLESS AND INDEMNIFY DESIGN PROFESSIONAL AGAINST ALL DAMAGES, CLAIMS AND LOSSES, INCLUDING DEFENSE COSTS, ARISING OUT OF ANY RESCUE OF CONSTRUCTION DOCUMENTS AND SPECIFICATIONS WITHOUT WRITTEN AUTHORIZATION OF DESIGN PROFESSIONAL.
7. THESE DRAWINGS SHALL BE READ IN CONJUNCTION WITH AND BE CONSIDERED TO BE PART OF A SEPARATE AND COMPLETE MECHANICAL SPECIFICATION.
8. ALL DIMENSIONS SHOWN ON THESE PLANS ARE APPROXIMATE AND MUST BE CONFIRMED ON SITE.
9. PRIOR TO OCCUPANCY, THE ENTIRE H.V.A.C. SYSTEMS SHALL BE BALANCED IN ACCORDANCE WITH ASSOCIATED AIR BALANCE COUNCIL (AABC) STANDARDS BY AN INDEPENDENT AIR BALANCE CONTRACTOR. CERTIFICATION SHALL BE PROVIDED BY CONTRACTOR FOR AIR AS APPLICABLE. SYSTEMS SHALL BE BALANCED AS INDICATED ON PLANS INCLUDING FRESH AIR VENTILATION. WHERE THERE IS A CONFLICT WITH MECHANICAL PLANS, AIR BALANCE CONTRACTOR SHALL NOTIFY ENGINEER PRIOR TO BALANCING OF SYSTEM. IF NOT, AIR BALANCE CONTRACTOR SHALL BEAR ALL COSTS INCURRED FOR WORK THAT MUST BE RE-BALANCED DUE TO CONFLICTS ON CONTRACT DOCUMENTS. CONTRACTOR SHALL PROVIDE THREE COPIES OF AIR BALANCE REPORT TO ENGINEER FOR APPROVAL.
10. FOR INACCESSIBLE AREAS CONTRACTOR SHALL PROVIDE ACCESS PANELS FOR ALL DAMPERS, EQUIPMENT, SMOKE DETECTORS, AND CONTROL DEVICES. THESE PANELS SHALL MATCH THE RATING OF THE WALL AND/OR CEILING THAT THEY ARE LOCATED IN. MINIMUM ACCESS PANEL SIZES SHALL BE AS FOLLOWS:

a. HAND ACCESS: 12"x12"

b. BODY ACCESS: 30"x30" MIN. WHERE A LARGER ACCESS SIZE IS REQUIRED DUE TO INSTALLATION CONSTRAINTS, THE CONTRACTOR SHALL DO SO AT NO ADDITIONAL COST AND SHALL NOTIFY THE ARCHITECT AND ENGINEER OF DEVIATIONS PRIOR TO INSTALLATION.
11. COORDINATE THE LOCATION OF ALL ROOF OPENINGS AND THE LOCATION OF ALL ROOF MOUNTED EQUIPMENT WITH THE STRUCTURAL AND ARCHITECTURAL PLANS PRIOR TO ANY INSTALLATION.
12. PLATFORMS, CURBS, AND FLASHINGS FOR MECHANICAL EQUIPMENT SHALL BE AS INDICATED ON THE STRUCTURAL AND ARCHITECTURAL PLANS, UNLESS NOTED OTHERWISE. WHERE THERE IS A CONFLICT WITH THE MECHANICAL PLANS THE CONTRACTOR SHALL NOTIFY THE ARCHITECT AND ENGINEER PRIOR TO FABRICATION AND INSTALLATION.
13. ALL EQUIPMENT, ACCESSORIES, AND RELATED PIPING SHALL BE INSTALLED IN STRICT ACCORDANCE WITH EQUIPMENT MANUFACTURER'S RECOMMENDATIONS. PROVIDE ALL FITTINGS, TRANSITIONS, DAMPERS, VALVES, AND OTHER DEVICES REQUIRED FOR A COMPLETE WORKABLE INSTALLATION.
14. MAINTENANCE LABEL SHALL BE AFFIXED TO ALL MECHANICAL EQUIPMENT AND A MAINTENANCE MANUAL SHALL BE PROVIDED FOR THE OWNER'S USE.
15. PROVIDE 85% MIN. EFFICIENCY THROWAWAY FILTERS FOR ALL AIR CONDITIONING UNITS. SEE EQUIPMENT SCHEDULE AND SPECIFICATIONS FOR TYPE. SIZES SHALL BE AS RECOMMENDED BY THE MANUFACTURER, UNLESS OTHERWISE SPECIFIED.
16. ALL EQUIPMENT WITH MOVING PARTS SHALL BE PROVIDED WITH FLEXIBLE DUCT AND PIPE CONNECTIONS.
17. ALL EQUIPMENT SHALL BE LABELED AS TO SPACE IT SERVES. SEE PLANS AND SPECIFICATIONS FOR IDENTIFICATION STANDARDS.
18. ALL HVAC EQUIPMENT SHALL BE CERTIFIED BY CALIFORNIA ENERGY COMMISSION (CEC) TO COMPLY WITH LATEST EFFICIENCY STANDARDS.
19. ALL FRESH AIR INTAKES SHALL MEET CODE REQUIRED CLEARANCES FROM EXHAUST, FLUE, FUEL BURNING APPLIANCE, AND PLUMBING VENT OUTLETS. FOR GAS/ELECTRIC AIR CONDITIONING UNITS WHERE CODE REQUIRED CLEARANCES ARE NOT MET, A FACTORY FLUE GAS DEFLECTOR AND EXTENSION SHALL BE USED TO MINIMIZE THESE CLEARANCES. CONTRACTOR SHALL DETERMINE LOCATIONS WHERE REQUIRED PRIOR TO BID. THIS SHALL BE PROVIDED AT NO ADDITIONAL COST.
20. ALL AIR HANDLING EQUIPMENT SERVING CONDITIONED SPACES SHALL PROVIDE CONTINUOUS FRESH AIR TO SPACES IN OCCUPIED MODE.
21. CONTRACTOR SHALL VERIFY ALL CLEARANCES AND AVAILABLE SPACE FOR DUCTWORK PRIOR TO ORDERING AND/OR FABRICATING MATERIAL.
22. CONTRACTOR TO SUBMIT ALL EQUIPMENT, DUCTWORK, AIR DISTRIBUTION DEVICES, AND OTHER ACCESSORIES TO ENGINEER FOR APPROVAL PRIOR TO ANY ORDERING OF SUCH ITEMS.
23. CONTRACTOR SHALL PROVIDE SHOP DRAWINGS WITHIN 45 DAYS OF AWARD OF CONTRACT. SEE DIV. 23 SPECIFICATIONS FOR REQUIREMENTS. IF SHOP DRAWINGS ARE NOT PROVIDED TO ENGINEER FOR APPROVAL, AND ANY CONFLICTS OCCUR BETWEEN TRADES, DURING CONSTRUCTION, & ETC. THEN CONTRACTOR SHALL BE RESPONSIBLE AND BEAR ALL COST INCURRED FOR ANY REVISIONS AT NO ADDITIONAL COST TO THE OWNER. THE OWNER AND ENGINEER SHALL BE NOTIFIED IMMEDIATELY PRIOR TO FABRICATION AND INSTALLATION OF ANY CONFLICTS BETWEEN TRADES, DURING CONSTRUCTION, & ETC.
24. PAINT EXPOSED SURFACES, WHETHER OR NOT COLORS ARE DESIGNATED IN SCHEDULES, EXCEPT WHERE A SURFACE OR MATERIAL IS SPECIFICALLY INDICATED NOT TO BE PAINTED OR IS TO REMAIN NATURAL, WHERE AN ITEM OR SURFACE IS NOT SPECIFICALLY MENTIONED, PAINT THE SAME AS SIMILAR ADJACENT MATERIALS OR SURFACES. IF COLOR OR FINISH IS NOT DESIGNATED, THE OWNER'S REPRESENTATIVE WILL SELECT FROM STANDARD COLORS OR FINISHES AVAILABLE.
- a. PAINTING INCLUDES FIELD PAINTING EXPOSED BARE AND COVERED PIPES AND DUCTS (INCLUDING COLOR CODING), HANGERS, EXPOSED STEEL AND IRON WORK, AND PRIMED METAL SURFACES OF MECHANICAL AND ELECTRICAL EQUIPMENT.
- CONTROLS ----
25. CONTROL SCHEMATICS ARE FOR SEQUENCE ONLY. REFER TO ELECTRICAL DRAWINGS AND SPECIFICATIONS FOR ALL ELECTRICAL DEVICES REQUIRED.
26. ALL LINE VOLTAGE WIRING SHALL BE INSTALLED IN CONDUIT. ALL LINE VOLTAGE CONDUIT AND WIRING, INCLUDING FINAL CONNECTIONS, SHALL BE FURNISHED AND INSTALLED BY THE ELECTRICAL CONTRACTOR AS INDICATED ON THE ELECTRICAL DRAWINGS OR SPECIFIED IN THE ELECTRICAL SECTION OF THE SPECIFICATIONS. ALL ELECTRICAL WORK SHALL BE INSTALLED IN ACCORDANCE WITH ALL APPLICABLE CODES AND REGULATIONS OF ALL GOVERNING BODIES HAVING JURISDICTION THEREOF.
27. ALL LOW VOLTAGE CONDUIT AND WIRING AS APPLICABLE, INCLUDING FINAL CONNECTIONS, SHALL BE FURNISHED AND INSTALLED BY THE MECHANICAL CONTRACTOR AS INDICATED ON THE MECHANICAL DRAWINGS OR SPECIFIED IN THE MECHANICAL SECTION OF THE SPECIFICATIONS.

a. ALL LOW VOLTAGE WIRING SHALL BE INSTALLED IN CONDUIT.

b. ALL LOW VOLTAGE WIRING SHALL BE PLENUM - RATED.

c. WHERE THE CONTROLS CONTRACTOR IS RETAINED BY THE OWNER, THEY SHALL BE RESPONSIBLE FOR THE FOLLOWING:

a. FURNISH AND INSTALL ALL DEVICES, WIRING, AND TERMINATIONS REQUIRED FOR A COMPLETE AND FUNCTIONAL INSTALLATION.

b. COORDINATE ALL WORK AND REQUIREMENTS WITH OTHER TRADES INCLUDING GENERAL, MECHANICAL, AND ELECTRICAL CONTRACTORS PRIOR TO BID.

c. CONTRACTOR SHALL FOLLOW ALL SUBMITTAL REQUIREMENTS PER DRAWINGS AND SPECIFICATIONS.
28. ALL THERMOSTATS SHALL BE OF THE ELECTRONIC, PROGRAMMABLE, AUTOMATIC CHANGE-OVER TYPE TO SEQUENCE HEATING OR COOLING. SET POINT RANGE SHALL BE 40° F. BETWEEN FULL HEATING AND COOLING. THEY SHALL HAVE CAPABILITY OF TERMINATING ALL HEATING AT A TEMPERATURE NO MORE THAN 70° F., AND COOLING AT A TEMPERATURE NOT LESS THAN 78° F. ADJUSTABLE TEMPERATURE DIFFERENTIAL SHALL BE 1½° F. CONTROL LIMITS SHALL BE FROM 55° F. TO 85° F. MOUNT AT THERMOSTAT PER DETAIL 1 ON SHEET M-201.
- NOTE:

a. THERMOSTATS THAT ARE PART OF AN ENERGY MANAGEMENT SYSTEM SHALL FOLLOW CONTROL SPECIFICATIONS AND DRAWING REQUIREMENTS.

b. SHOULD THE LOCATION OF THE THERMOSTAT NOT MEET ADA HEIGHT REQUIREMENTS DUE TO OBSTRUCTIONS, THEN AN ALTERNATE LOCATION SHALL BE PROPOSED OR REQUESTED BY CONTRACTOR THAT SHALL BE APPROVED BY ENGINEER AND ARCHITECT.

29. CONTROLS CONTRACTOR AND AIR BALANCE CONTRACTOR SHALL COORDINATE WORK AND PERFORM NECESSARY TASKS AS REQUIRED TO OBTAIN AIR AND WATER FLOW QUANTITIES FOR SYSTEMS SHOWN HEREIN.

30. CONTROLS SHALL BE PROVIDED TO PROVIDE THE MINIMUM RATE OF OUTDOOR AIR REQUIRED BY THE STATE ENERGY REGULATIONS.

---- AIR DISTRIBUTION ----

31. ALL DUCTWORK SHALL BE SHEET METAL CONSTRUCTED OR SPIRAL, ERECTED, AND TESTED IN ACCORDANCE WITH THE MOST RESTRICTIVE OF LOCAL REGULATIONS, PROCEDURES DETAILED IN THE ASHRAE HANDBOOK OF FUNDAMENTALS, CHAPTER 6 OF THE MECHANICAL CODE, OR THE APPLICABLE STANDARDS ADOPTED BY THE SHEET METAL AND AIR CONDITIONING CONTRACTORS NATIONAL ASSOCIATION.

32. DUCTWORK HANDLING CONDITIONED AIR SHALL BE INSULATED OR LINED AS INDICATED ON DRAWINGS. SUPPLY AND RETURN DUCT INSULATION SHALL BE MIN. 1½" THICK, ¾" LB./CUBIC FT. DENSITY AND HAVE A MIN. VALUE OF R-8 WHERE LOCATED IN ONE OR MORE OF THE FOLLOWING SPACES:

a. OUTDOORS, OR

b. IN A SPACE BETWEEN THE ROOF AND AN INSULATED CEILING, OR

c. IN A SPACE DIRECTLY UNDER A ROOF WITH FIXED VENTS OR OPENINGS TO THE OUTSIDE OR UNCONDITIONED SPACES, OR

d. IN AN UNCONDITIONED CRAWLSPACE; OR

e. IN OTHER UNCONDITIONED SPACES

OTHERWISE PROVIDE R-8 WHEN LOCATED IN CONDITIONED ATTIC SPACES ABOVE CEILINGS. ALL DUCTWORK EXPOSED ON ROOF SHALL BE INTERNALLY LINED WITH 1½" THICK, 1½ LB./CUBIC FT. DENSITY DUCT LINER UNLESS OTHERWISE INDICATED OR SPECIFIED. ALL DUCT SIZES ARE SHEET METAL SIZES. ALL DUCT JOINTS SHALL BE SEALED PER CHAPTER 6 MECHANICAL CODE REQUIREMENTS. PROVIDE PIPING AND DUCT INSULATION IN ACCORDANCE WITH THE LATEST STANDARDS OF THE CALIFORNIA ENERGY COMMISSION.

33. ALL INSULATION SHALL HAVE A FLAME SPREAD OF NOT MORE THAN 25 AND A SMOKE DENSITY NOT EXCEEDING 50.

34. MANUAL VOLUME DAMPER SHALL BE PROVIDED IN ALL DUCT BRANCHES TO INDIVIDUAL DIFFUSERS, GRILLES, AND REGISTERS, AS WELL AS FRESH AIR INTAKE DUCTS. DAMPERS SHALL BE LOCATED AT THE BRANCH DUCT LOCATIONS. MECHANICAL CONTRACTOR SHALL COORDINATE LOCATIONS OF DAMPERS WITH AIR BALANCE CONTRACTOR PRIOR TO BID, SO THEY ARE ACCESSIBLE PRIOR TO BID, SO THEY ARE ACCESSIBLE PRIOR TO INSTALLATION. OPPOSED BLADE DAMPERS SHALL NOT BE PERMITTED UNLESS NOTED OTHERWISE.

---- EXISTING CONDITIONS ----

35. BEFORE BIDDING ON THIS WORK, THE CONTRACTOR SHALL MAKE A CAREFUL EXAMINATION OF THE PREMISES, EXISTING EQUIPMENT AND SERVICES. HE SHALL DEFINITELY DETERMINE IN ADVANCE, THE METHODS OF INSTALLING AND CONNECTING THE NEW EQUIPMENT, DUCTWORK, AND PIPING THE MEANS TO BE PROVIDED FOR GETTING THE EQUIPMENT AND MATERIALS INTO PLACE AND SHALL MAKE HIMSELF THOROUGHLY FAMILIAR WITH ALL OF THE REQUIREMENTS OF THE PROJECT. FAILURE TO VISIT THE SITE WILL IN NO WAY RELIEVE THE CONTRACTOR OF HIS CONTRACTOR OF THE NECESSITY OF FURNISHING ANY MATERIAL OR PERFORMING ANY WORK THAT MAY BE REQUIRED TO COMPLETE THE WORK IN ACCORDANCE WITH THE DRAWINGS AND SPECIFICATIONS. THIS ADDITIONAL SHALL BE PERFORMED WITHOUT ADDITIONAL COST TO THE OWNER.

36. CONTRACTOR SHALL VERIFY PRIOR TO CONSTRUCTION THE CONDITION OF EXISTING EQUIPMENT, DUCTWORK, ASSOCIATED CONTROLS, PAID T-SLOTS, SHOULD ANY OF THESE ITEMS NOT BE PERFORMING SATISFACTORILY OR MALFUNCTIONING. CONTRACTOR SHALL NOTIFY TENANT AND/OR OWNER AND PROVIDE A COST TO ENSURE PROPER OPERATION PRIOR TO COMPLETION OF WORK.

37. BEFORE COMMENCEMENT OF WORK, THE CONTRACTOR SHALL VERIFY THE EXACT LOCATIONS AND DIMENSIONS OF ALL EXISTING EQUIPMENT AND ELECTRICAL SERVICES IN THE AREA OF CONSTRUCTION AND NOTIFY THE ENGINEER AND ARCHITECT OF ANY DISCREPANCIES.

38. ALL CONNECTIONS AND DISCONNECTIONS TO EXISTING EQUIPMENT SHALL BE MADE IN SUCH A MANNER THAT INTERRUPTION TIME SHALL BE KEPT TO A MINIMUM. THE CONTRACTOR SHALL GIVE THE OWNER'S REPRESENTATIVE SUFFICIENT NOTICE OF SUCH INTERRUPTION AND THE ACTUAL SHUTDOWN TIME SHALL BE AT A TIME DESIGNATED BY THE OWNER'S REPRESENTATIVE.

40. ALL VALVES, UNIONS, ETC. TO BE SAME SIZE AS PIPE UNLESS OTHERWISE INDICATED ON DRAWINGS.

41. CONNECTION BETWEEN INCOMPATIBLE MATERIALS ABOVE GRADE AND INSIDE BUILDING SHALL BE MADE WITH TWO (2) DIELECTRIC UNIONS SEPARATED BY A TWELVE INCH (12") SECTION OF RED BRASS PIPE.

42. ALL PLUMBING WORKS SHALL BE INSTALLED SO AS TO AVOID INTERFERENCE WITH ELECTRICAL AND MECHANICAL EQUIPMENT AND STRUCTURAL FRAMING.

43. ALL WORK AND MATERIAL SHALL BE PERFORMED AND INSTALLED IN COMPLIANCE WITH CALIFORNIA PLUMBING CODE 2022.

44. ANY ALTERATION TO A STRUCTURAL MEMBER, SUCH AS CUTTING, BORING, BRAZING, DRILLING, WELDING, ETC. SHALL HAVE PRIOR WRITTEN APPROVAL OF ARCHITECT, STRUCTURAL ENGINEER AND DSA.

MECHANICAL SHEET LIST

SHEET NUMBER	SHEET TITLE
M0.01	MECHANICAL GENERAL NOTES AND DESIGN CRITERIA
M0.02	MECHANICAL LEGEND
M0.03	MECHANICAL SCHEDULES
M1.01	MECHANICAL BUILDINGS REFERENCE PLAN
MD2.01	BUILDINGS B, C, & E MECHANICAL DEMOLITION FLOOR PLANS
MD2.02	BUILDINGS A & D MECHANICAL DEMOLITION FLOOR PLANS
MD2.03	BUILDINGS B, C, & E MECHANICAL DEMOLITION ROOF PLANS
MD2.04	BUILDINGS A & D MECHANICAL DEMOLITION ROOF PLANS
M2.01	BUILDINGS B, C, & E MECHANICAL NEW WORK FLOOR PLANS
M2.02	BUILDINGS A & D MECHANICAL NEW WORK FLOOR PLANS
M2.03	BUILDINGS B, C, & E MECHANICAL NEW WORK ROOF PLANS
M2.04	BUILDINGS A & D MECHANICAL NEW WORK ROOF PLANS
M3.01	MECHANICAL DETAILS
M3.02	MECHANICAL DETAILS
M4.01	MECHANICAL EMS CONTROL DIAGRAMS
M5.01	MECHANICAL TITLE 24 FORMS
M5.02	MECHANICAL TITLE 24 FORMS

APPLICABLE CODES AND STANDARDS

LIST OF APPLICABLE CODES

2025 CALIFORNIA ADMINISTRATIVE CODE (CAC), PART 1, TITLE 24 CCR
2022 CALIFORNIA BUILDING CODE (CBC), PART 2, TITLE 24 CCR
2022 CALIFORNIA ELECTRICAL CODE (CEC), PART 3, TITLE 24 CCR
2022 CALIFORNIA MECHANICAL CODE (CMC), PART 4, TITLE 24 CCR
2022 CALIFORNIA PLUMBING CODE (CPC), PART 5, TITLE 24 CCR
2022 CALIFORNIA ENERGY CODE, PART 6, TITLE 24 CCR
2022 CALIFORNIA FIRE CODE (CFC), PART 9, TITLE 24 CCR
2022 CALIFORNIA EXISTING BUILDING CODE (CEBC), PART 10, TITLE 24 CCR
2022 CALIFORNIA GREEN BUILDING STANDARDS CODE (CALGREEN), PART 11, TITLE 24 CCR
2022 CALIFORNIA REFERENCED STANDARDS CODE, PART 12, TITLE 24 CCR
TITLE 19 CCR, PUBLIC SAFETY, STATE FIRE MARSHAL REGULATIONS

APPLICABLE STANDARDS

FOR A LIST OF APPLICABLE STANDARDS, INCLUDING CALIFORNIA AMENDMENTS TO THE NFPA STANDARDS, REFER TO CBC CHAPTER 35 AND CFC CHAPTER 80.

MEP COMPONENT ANCHORAGE NOTE

APPLICABLE CODE: 2022 CBC

MEP COMPONENT ANCHORAGE NOTE

ALL MECHANICAL, PLUMBING, AND ELECTRICAL COMPONENTS SHALL BE ANCHORED AND INSTALLED PER THE DETAILS ON THE DSA-APPROVED CONSTRUCTION DOCUMENTS. THE FOLLOWING COMPONENTS SHALL BE ANCHORED OR BRACED TO MEET THE FORCE AND DISPLACEMENT REQUIREMENTS PRESCRIBED IN THE 2022 CBC SECTIONS 1617A.1.18 THROUGH 1617A.1.26 AND ASCE 7-16 CHAPTERS 13, 26, AND 30:

1. ALL PERMANENT EQUIPMENT AND COMPONENTS.
2. TEMPORARY, MOVABLE OR MOBILE EQUIPMENT THAT IS PERMANENTLY ATTACHED (E.G., HARD WIRED) TO THE BUILDING UTILITY SERVICES SUCH AS ELECTRICITY, GAS OR WATER. "PERMANENTLY ATTACHED" SHALL INCLUDE ALL ELECTRICAL CONNECTIONS EXCEPT PLUGS FOR 110/220 VOLT RECEPTACLES HAVING A FLEXIBLE CABLE.
3. TEMPORARY, MOVABLE OR MOBILE EQUIPMENT WHICH IS HEAVIER THAN 400 POUNDS OR HAS A CENTER OF MASS LOCATED 4 FEET OR MORE ABOVE THE ADJACENT FLOOR OR ROOF LEVEL THAT DIRECTLY SUPPORT THE COMPONENT IS REQUIRED TO BE RESTRAINED IN A MANNER APPROVED BY DSA.

THE FOLLOWING MECHANICAL AND ELECTRICAL COMPONENTS SHALL BE POSITIVELY ATTACHED TO THE STRUCTURE BUT NEED NOT DEMONSTRATE DESIGN COMPLIANCE WITH THE REFERENCES NOTED ABOVE. THESE COMPONENTS SHALL HAVE FLEXIBLE CONNECTIONS PROVIDED BETWEEN THE COMPONENT AND ASSOCIATED DUCTWORK, PIPING, AND CONDUIT. FLEXIBLE CONNECTIONS MUST ALLOW MOVEMENT IN BOTH TRANSVERSE AND LONGITUDINAL DIRECTIONS:

- A. COMPONENTS WEIGHING LESS THAN 400 POUNDS AND HAVING A CENTER OF MASS LOCATED 4 FEET OR LESS ABOVE THE ADJACENT FLOOR OR ROOF LEVEL THAT DIRECTLY SUPPORT THE COMPONENT.
- B. COMPONENTS WEIGHING LESS THAN 20 POUNDS, OR IN THE CASE OF DISTRIBUTED SYSTEMS, LESS THAN 5 POUNDS PER FOOT, WHICH ARE SUSPENDED FROM A ROOF OR FLOOR OR HUNG FROM A WALL.

THE ANCHORAGE OF ALL MECHANICAL, ELECTRICAL AND PLUMBING COMPONENTS SHALL BE SUBJECT TO THE APPROVAL OF THE DESIGN PROFESSIONAL IN GENERAL RESPONSIBLE CHARGE OR STRUCTURAL ENGINEER DELEGATED RESPONSIBILITY AND ACCEPTANCE BY DSA. THE PROJECT INSPECTOR WILL VERIFY THAT ALL COMPONENTS AND EQUIPMENT HAVE BEEN ANCHORED IN ACCORDANCE WITH THE ABOVE REQUIREMENTS.

APPLICABLE CODE: 2022 CBC

PIPING, DUCTWORK, AND ELECTRICAL DISTRIBUTION SYSTEM BRACING NOTE

PIPING, DUCTWORK, AND ELECTRICAL DISTRIBUTION SYSTEMS SHALL BE BRACED TO COMPLY WITH THE FORCES AND DISPLACEMENTS PRESCRIBED IN ASCE 7-16 SECTION 13.3 AS DEFINED IN ASCE 7-16 SECTIONS 13.6.5, 13.6.6, 13.6.7, 13.6.8; AND 2022 CBC, SECTIONS 1617A.1.24, 1617A.1.25 AND 1617A.1.26.

THE METHOD OF SHOWING BRACING AND ATTACHMENTS TO THE STRUCTURE FOR THE IDENTIFIED DISTRIBUTION SYSTEM ARE AS NOTED BELOW. WHEN BRACING AND ATTACHMENTS ARE BASED ON A PREAPPROVED INSTALLATION GUIDE (E.G., HCAI OPM FOR 2013 CBC OR LATER), COPIES OF THE BRACING SYSTEM INSTALLATION GUIDE OR MANUAL SHALL BE AVAILABLE ON THE JOBSITE PRIOR TO THE START OF AND DURING THE HANGING AND BRACING OF THE DISTRIBUTION SYSTEMS. THE STRUCTURAL ENGINEER OF RECORD SHALL VERIFY THE ADEQUACY OF THE STRUCTURE TO SUPPORT THE HANGER AND BRACE LOADS.

MECHANICAL PIPING (MP), MECHANICAL DUCTS (MD), PLUMBING PIPING (PP), ELECTRICAL DISTRIBUTION SYSTEMS (E):

MP ☒ MD ☐ PP ☒ E ☐ OPTION 1: DETAILED ON THE APPROVED DRAWINGS WITH PROJECT SPECIFIC NOTES AND DETAILS.

MP ☐ MD ☐ PP ☐ E ☐ OPTION 2: SHALL COMPLY WITH HCAI (OSHPD) PREAPPROVAL (OPM #) # _____, AS INCLUDED IN THESE DRAWINGS WITH PROJECT-SPECIFIC NOTES AND DETAILS.

DESIGN CRITERIA

1. REPLACE EXISTING GAS FIRED FURNACES AND DX COOLING SPLIT SYSTEMS IN-KIND FOR BUILDINGS A, B, C, D, & E
2. RE-CONNECT NEW HVAC EQUIPMENT TO EXISTING CAMPUS EMS.
3. TEST, ADJUST, AND BALANCE (TAB) THE AIR DISTRIBUTION SYSTEM INCLUDING EQUIPMENT AND CONTROLS TO MAINTAIN BUILDINGS PRESSURIZATION AND TEMPERATURE CONTROL.
4. RE-CONNECT NATURAL GAS PIPING FOR GAS FIRED FURNACES.
5. PROVIDE CONDENSATE PIPING FOR NEW COOLING COILS AND DISCHARGE TO AN APPROVED DISPOSAL AREA

CARBON MONOXIDE STATEMENT

CARBON MONOXIDE DETECTION SYSTEM NOT REQUIRED PER DSA IR 9-2, EXCEPTION 2.2.1 PER THE CALIFORNIA EXISTING BUILDING CODE. THIS GROUP E PROJECT WAS CONSTRUCTED BEFORE ADOPTION OF THE 2016 CALIFORNIA BUILDING STANDARDS CODE.

ACCEPTANCE TESTING


1. THE CALIFORNIA ENERGY CODE SECTION 10-103 REQUIRES ACCEPTANCE TESTING ON ALL NEWLY INSTALLED MECHANICAL SYSTEMS AND PROCESS EQUIPMENT AFTER INSTALLATION AND BEFORE PROJECT COMPLETION. AN ACCEPTANCE TEST IS A FUNCTIONAL PERFORMANCE TEST TO HELP ENSURE THAT NEWLY INSTALLED EQUIPMENT IS OPERATING AND IN COMPLIANCE WITH THE ENERGY CODE.
2. MECHANICAL SYSTEM ACCEPTANCE TESTS MUST BE PERFORMED BY A CERTIFIED MECHANICAL ATT FOR PROJECTS SUBMITTED ON OR AFTER OCTOBER 1, 2021.
3. PROCESS EQUIPMENT ACCEPTANCE TESTS SHALL BE PERFORMED BY THE INSTALLING CONTRACTOR, ENGINEER/ARCHITECT OF RECORD OR THE OWNER'S AGENT.
4. A LISTING OF CERTIFIED ATT CAN BE FOUND AT: [HTTPS://WWW.ENERGY.CA.GOV/PROGRAMS-AND-TOPICS/PROGRAMS/ACCEPTANCE-TEST-TECHNICIAN-CERTIFICATION-PROVIDER-PROGRAM/ACCEPTANCE-TEST-TECHNICIAN-CERTIFICATION-PROVIDER-PROGRAM](https://www.energy.ca.gov/programs-and-topics/programs/acceptance-test-technician-certification-provider-program/acceptance-test-technician-certification-provider-program). THE ACCEPTANCE TESTING PROCEDURES MUST BE REPEATED, AND DEFICIENCIES MUST BE CORRECTED BY THE BUILDER OR INSTALLING CONTRACTOR UNTIL THE CONSTRUCTION/INSTALLATION OF THE SPECIFIED SYSTEMS CONFORM AND PASS THE REQUIRED ACCEPTANCE CRITERIA.
5. PROJECT INSPECTORS WILL COLLECT THE FORMS TO CONFIRM THAT THE REQUIRED ACCEPTANCE TESTS HAVE BEEN COMPLETED.

BID ALTERNATE

BASE BID: DUCT CLEANING FOR ALL BLDGS EXISTING AIR DISTRIBUTION ABOVE ACCT CEILING TILING. SEE SPECIFICATION 23 00 00 HVAC FOR ADDITIONAL INFORMATION.

BID ALTERNATE #1:

-REPLACE BLDGS. C & D EXISTING AIR DISTRIBUTION WITH NEW
-ALL OTHER BLDGS EXISTING AIR DISTRIBUTION SHALL BE CLEANED PER BASE BID.

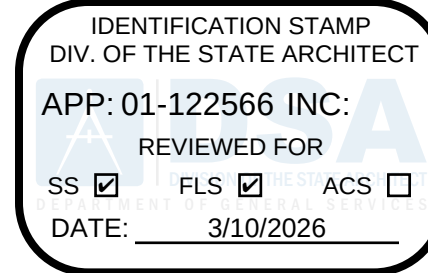

#	Revisions		
Delta	Date	Revisions	By



Consulting Engineers
5277 College Avenue
Oakland, CA 94618
Telephone (510) 837-9182



HY Architects Project number: Project Number

Facility
SKYLINE ELEMENTARY SCHOOL
55 CHRISTEN AVE, DALY CITY, CA 94015

Project
HVAC REPLACEMENT

Sheet Title

MECHANICAL GENERAL NOTES
AND DESIGN CRITERIA

Client Project Number: 0000.0

Scale: Not to Scale
Drawn By: CC
Checked By: AK
Issue Date:
Revit Version: 2023
Sheet of

M0.01

3/20/2023 3:12:50 PM M:\P - PROJECTS\2025\002-25-0001 SFUSD SKYLINE ES\02_MECH



IF THIS SHEET IS NOT 30"x42", IT IS
A REDUCED PRINT SCALE ACCORDINGLY

IDENTIFICATION STAMP
DIV. OF THE STATE ARCHITECT
APP: 01-122566 INC:
REVIEWED FOR
SS ☒ FLS ☒ ACS ☐
DATE: 3/10/2026



#	Revisions
Delta	Date Revisions By



Consulting Engineers
5277 College Avenue
Oakland, CA 94618
Telephone (510) 837-9182

This document is the property of the Owner and is not to be used without their written permission



HY HIBSER YAMAUCHI
Architects, Inc.
300 - 27th Street
Oakland, CA 94612
510.446.2222 tel | 510.446.2211 fax

HY Architects Project number: Project Number

Facility
SKYLINE ELEMENTARY SCHOOL
55 CHRISTEN AVE, DALY CITY, CA 94015

Project
HVAC REPLACEMENT

Sheet Title

MECHANICAL LEGEND

Client Project Number: 0000.0

Scale: Not to Scale

Drawn By: CC

Checked By: AK

Issue Date:

Revit Version: 2023

Sheet

CC

AK

 

Sheet of

M0.02

LEGEND

SYMBOL	ABBR.	DESCRIPTION	SYMBOL	ABBR.	DESCRIPTION	ABBR.	DESCRIPTION	SYMBOL	ABBR.	DESCRIPTION	SYMBOL	ABBR.	DESCRIPTION
	-	SUPPLY AIR RISER		ME	ITEMS FURNISHED BY MECHANICAL CONTRACTOR AND INSTALLED BY ELECTRICAL CONTRACTOR.	DSA	DEPARTMENT OF STATE ARCHITECTS		LWC	LIGHT WEIGHT CONCRETE		SM/SMS	SHEET METAL / SHEET METAL SCREW
	-	RETURN AIR RISER		DWG	DRAWING	MFR	MANUFACTURER		SOO	SEQUENCE OF OPERATION			
	-	EXHAUST AIR RISER		EER	ENERGY EFFICIENCY RATIO	MAX	MAXIMUM		SOV	SHUT-OFF VALVE			
	SAG	SUPPLY AIR GRILLE		DSD	DUCT SMOKE DETECTOR	MBH	THOUSAND BRITISH THERMAL UNITS		SP	STATIC PRESSURE			
	RAG	RETURN AIR GRILLE		MEP	MECHANICAL, ELECTRICAL AND PLUMBING	SQ	SQUARE		SQ.FT.	SQUARE FEET			
	EAG	EXHAUST AIR GRILLE		MTL	METAL	MCA	MINIMUM CIRCUIT AMPACITY		SS	STAINLESS STEEL			
	SWR	SIDEWALL REGISTER		EA	EXHAUST AIR/ EACH	MECH	MECHANICAL		SSD	SEE STRUCTURAL DRAWINGS			
	(L)	LINED DUCTWORK		EAD	EXHAUST AIR DUCT	MERV	MINIMUM EFFICIENCY REPORTING VALUE		STD	STANDARD			
	-	FLEXIBLE CONNECTION		EAT	ENTERING AIR TEMPERATURE	MIN	MINIMUMMINUTE		STPT	SETPOINT			
	FC	FLEXIBLE CONNECTION		EOR	ENGINEER OF RECORD	MOP	MINIMUM OVERCURRENT PROTECTION		SYM	SYMBOL			
	-	NEW DUCT (SEE PLAN)		EMS	ENERGY MANGEMENT SYSTEM	MHP	MOTOR HORSE POWER		T-24	TITLE 24			
	-	EXISTING DUCT (SEE PLAN)		ESP	EXTERNAL STATIC PRESSURE	MTG	MOUNTING		TCP	TEMPERATURE CONTROL PANEL			
	-	DEMO DUCT (SEE PLAN)		MP	MIXING PLENUM	(N)	NEW		TEMP	TEMPERATURE			
	MVD	MANUAL VOLUME DAMPER		ADDTL	ADDITIONAL	ERU	ENERGY RECOVERY UNIT		TOP	TOP OF PIPE			
	BDD	BACKDRAFT DAMPER		ADJ	ADJUSTABLE	EWT	ENTERING WATER TEMPERATURE		T-STAT	THERMOSTAT			
	SFD	SMOKE / FIRE DAMPER		AHU	AIR HANDLING UNIT	EX	EXAMPLE		TXV	THERMOSTATIC EXPANSION VALVE			
	FD	FIRE DAMPER		AI	ANALOG INPUT	EXT	EXTERNAL/EXTERIOR		TYP	TYPICAL			
	DL	DOOR LOUVER		AO	ANALOG OUTPUT	FEI	FAN ENERGY INDEX		U.L.	UNITED LABORATORIES			
	U.C.	UNDERCUT DOOR 3/4"		APD	AIR PRESSURE DROP	FLA	FULL LOAD AMPERAGE		V	VOLT			
	RS	REFRIGERANT SUCTION LINE		ASCE	AMERICAN SOCIETY OF CIVIL ENGINEERS	FLR	FLOOR		VAV	VARIABLE AIR VOLUME			
	RL	REFRIGERANT LIQUID LINE		ATR	ALL-THREADED ROD	FPI	FINS PER INCH		OPNG	OPENING		VD	MANUAL VOLUME DAMPER
	CD	CONDENSATE DRAIN		ATT	ACCEPTANCE TEST TECHNICIAN	FO	FIELD ORDER		OBD	OPPOSED BLADE DAMPER		VELO	VELOCITY
	-	STRAINER		BDD	BACKDRAFT DAMPER	FPS	FEET PER SECOND		OSHPD	DEVELOPMENT		VFD	VARIABLE FREQUENCY DRIVE
	-	THERMOMETER		BG	BELOW GROUND	FPM	FEET PER MINUTE		OSA	OUTSIDE AIR		VOL	VOLUME
	-	SHUTOFF VALVE		BHP	BRAKE HORSE POWER	FSC	FAN SPEED CONTROL		O.D.	OUTSIDE DIAMETER		VTR	VENT THRU ROOF
	-	CHECK VALVE		BLKG	BLOCKING	FT	FEET		NR	NETWORK ROUTER		W	WIDTH
	-	BALL VALVE		BOP	BOTTOM OF PIPE	GA	GAUGE		LWT	LEAVING WATER TEMPERATURE		W/	WITH
	-	DIRECTION OF FLOW		BTUH	BRITISH THERMAL UNITS	GALV	GALVANIZED		PH	PHASE		W/O	WORK ORDER
	-	REDUCER OR INCREASER		CA	CALIFORNIA	GPM	GALLONS PER MINUTE		PLATE			WB	WET BULB
	-	MANUAL AIR VENT		CAV	CONSTANT AIR VOLUME	G.C.	GENERAL CONTRACTOR		PT	POINT		W.G.	WATER GAUGE
	-	TOP CONNECTION, 45° OR 90°		CBC	CALIFORNIA BUILDING CODE	HDG	HOT DIPPED GALVANIZED		PLF	POUND PER LINEAR FEET		WPD	WATER PRESSURE DROP
	-	BOTTOM CONNECTION, 45° OR 90°		CC	CONTROL CONTRACTOR	HOA	HAND-OFF-AUTO		PSI	POUND PER SQUARE INCH		WT	WEIGHT
	-	SIDE CONNECTION		CCR	CALIFORNIA CODE OF REGULATIONS	HHW	HEATING HOT WATER		PC	PRE-CAST			
	-	CAPPED OUTLET		C.D.	CEILING DIFFUSER	HTG	HEATING		PD	PRESSURE DROP			
	-	RISE OR DROP IN PIPE		CFM	CUBIC FEET PER MINUTE	HP	HORSE POWER		PRESS.	PRESSURE			
	-	UNION		CLG	COOLING	HWR	HOT-WATER RETURN		PERFOR	PERFORATED			
	HHWR	HEATING HOT-WATER RETURN		CLR	CLEAR	HVAC	HEATING VENTILATION AND AIR CONDITIONING		PID	PROPORTIONAL INTEGRAL DERIVATIVE			
	HHWS	HEATING HOT-WATER SUPPLY		CONTR	CONTRACTOR	HZ	HERTZ		PS	PRE-STRESSED			
	CHWS	CHILLED WATER SUPPLY		CONC	CONCRETE	HWS	HOT-WATER SUPPLY		QTY	QUANTITY			
	CHWR	CHILLED WATER RETURN		COP	COEFFICIENT OF PERFORMANCE	I.D.	INSIDE DIAMETER		R	RELOCATED			
	S.D.	SMOKE DETECTOR		CONT.	CONTINUATION	IAPMO	INTERNATIONAL ASSOCIATION OF PLUMBING AND MECHANICAL OFFICIALS		RAD	RETURN AIR DUCT			
	P.O.C.	POINT OF CONNECTION		CU	CONDENSER UNIT	IN	INCHES		REQ'D	REQUIRED			
	P.O.D.	POINT OF DEMOLITION		CV	VALVE FLOW COEFFICIENT	IMP	IMPELLER		RG	REFRIGERANT GAS			
	T-STAT	THERMOSTAT		D	DEPTH	INFO	INFORMATION		RL	REFRIGERANT LIQUID			
	H	HUMIDISTAT		D'	DIAMETER INCHES	IN W.G	INCHES WATER GAUGE		RND	ROUND			
	TS	TEMPERATURE SENSOR		DB	DRY BULB	L	LENGTH		RPM	REVOLUTIONS PER MINUTE			
	OS	OVERRIDE SWITCH		Dba	A-WEIGHTED DECIBEL	IN W.C./WVG	INCH WATER COLUMN		SA	SUPPLY AIR			
	PD	PRESSURE DIFFERENTIAL SWITCH		DDC	DIRECT DIGITAL CONTROL	L X W X H	LENGTH X WIDTH X HEIGHT		SB	SOLID BLOCKING/SIMPSON BOLT			
	S	SWITCH		DEFL.	DEFLECTION	"L	LINER THICKNESS IN INCHES		SHT.	SHEET			
	E	ITEMS FURNISHED AND INSTALLED BY ELECTRICAL CONTRACTOR AS SPECIFIED ON THE ELECTRICAL CONTRACT DOCUMENTS		DEG	DEGREE	DO	DIGITAL OUTPUT		SCCR	SHORT CIRCUIT CURRENT RATING			
	M	ITEMS FURNISHED AND INSTALLED BY MECHANICAL CONTRACTOR AS SPECIFIED ON THE MECHANICAL CONTRACT DOCUMENTS		DI	DIGITAL INPUT	LAT	LEAVING AIR TEMPERATURE		SCH	SCHEDULE			
	EM	ITEMS FURNISHED BY ELECTRICAL CONTRACTOR AND INSTALLED BY MECHANICAL CONTRACTOR.		DIA	DIAMETER	LAT.	LATERAL		S	STRUCTURAL			
				DIS	DISCHARGE	LBS	POUNDS		SDS	SELF DRILLING SCREW			
									SEER	SEASONAL ENERGY EFFICIENCY RATIO			
									SAD	SUPPLY AIR DUCT			
									SEOR	STRUCTURAL ENGINEER OF RECORD			

NOTE: NOT ALL ITEMS SHOWN ON THE LEGEND LIST MAY BE USED.

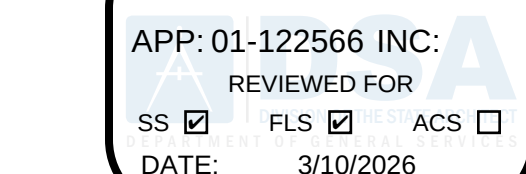

Delta	Date	Revisions	By
-------	------	-----------	----

INDOOR GAS UPFLOW FURNACE SCHEDULE - BUILDINGS A, B, C, D, E																		OUTDOOR CONDENSING UNIT SCHEDULE - BUILDINGS A, B, C, D, E																	
SYM	MFR & MODEL #	AREA SERVICED	HEATING CAPACITY		AFUE(%)	CFM	OSA CFM	ESP (IN WG)	ELECTRICAL				WT (LBS)	INTERLOCK WITH	OUTDOOR UNIT	CONTROL DETAIL	ANCHORAGE DETAIL	REMARKS	SYM	MFR & MODEL #	TONS	AREA SERVICED	COOLING CAPACITY	SEER	ELECTRICAL				WEIGHT (LBS)	INDOOR UNIT	CONTROL DETAIL	ANCHORAGE DETAIL	REMARKS		
			INPUT	OUTPUT					V	PH	MCA	MOCP													V	PH	MCA	MOCP							
<div><div>F</div><div>A.1</div></div>	CARRIER 58SU5B100M21--22	BUILDING A	100,000	97,000	95	1645	525	1.50	115	1	13.8	20	170	<div><div>EC</div><div>A.1</div></div>	<div><div>CU</div><div>A.1</div></div>	<div><div>1</div><div>M4.01</div></div>	<div><div>4</div><div>M3.01</div></div>	1,2,3,4,5,6,8,10,11	<div><div>CU</div><div>A.1</div></div>	CARRIER 26SCA560	5.0	BUILDING A	60,000	15.0	230	1	31.4	50	216	<div><div>F</div><div>1.1</div></div>	<div><div>1</div><div>M4.01</div></div>	<div><div>3</div><div>M3.01</div></div>	1,2,3,4,5		
<div><div>F</div><div>B.1</div></div>	CARRIER 59SU5B080M21--20	BUILDING B	80,000	78,000	95	1200	425	1.20	115	1	13.8	20	161	<div><div>EC</div><div>B.1</div></div>	<div><div>CU</div><div>B.1</div></div>	<div><div>1</div><div>M4.01</div></div>	<div><div>14</div><div>M3.01</div></div>	1,2,3,4,5,6,7,8,9,10,11	<div><div>CU</div><div>B.1</div></div>	CARRIER 26SCA536	3.0	BUILDING B	36,000	15.5	230	1	17.6	30	177	<div><div>F</div><div>1.2</div></div>	<div><div>1</div><div>M4.01</div></div>	<div><div>4</div><div>M3.01</div></div>	1,2,3,4,5		
<div><div>F</div><div>B.2</div></div>	CARRIER 59SU5B080M21--20	BUILDING B	80,000	78,000	95	1200	425	1.20	115	1	13.8	20	161	<div><div>EC</div><div>B.2</div></div>	<div><div>CU</div><div>B.2</div></div>	<div><div>1</div><div>M4.01</div></div>	<div><div>14</div><div>M3.01</div></div>	1,2,3,4,5,6,7,8,10,11	<div><div>CU</div><div>B.2</div></div>	CARRIER 26SCA536	3.0	BUILDING B	36,000	15.5	230	1	17.6	30	177	<div><div>F</div><div>1.3</div></div>	<div><div>1</div><div>M4.01</div></div>	<div><div>3</div><div>M3.01</div></div>	1,2,3,4,5		
<div><div>F</div><div>C.1</div></div>	CARRIER 59SU5B080M21--20	BUILDING C	80,000	78,000	95	1200	350	1.00	115	1	13.8	20	161	<div><div>EC</div><div>C.1</div></div>	<div><div>CU</div><div>C.1</div></div>	<div><div>1</div><div>M4.01</div></div>	<div><div>5</div><div>M3.01</div></div>	1,2,3,4,5,6,8,10,11	<div><div>CU</div><div>C.1</div></div>	CARRIER 26SCA536	3.0	BUILDING C	36,000	15.5	230	1	17.6	30	177	<div><div>F</div><div>1.4</div></div>	<div><div>1</div><div>M4.01</div></div>	<div><div>3</div><div>M3.01</div></div>	1,2,3,4,5		
<div><div>F</div><div>C.2</div></div>	CARRIER 59SU5B080M21--20	BUILDING C	80,000	78,000	95	1200	345	1.00	115	1	13.8	20	161	<div><div>EC</div><div>C.2</div></div>	<div><div>CU</div><div>C.2</div></div>	<div><div>1</div><div>M4.01</div></div>	<div><div>5</div><div>M3.01</div></div>	1,2,3,4,5,6,8,10,11	<div><div>CU</div><div>C.2</div></div>	CARRIER 26SCA536	3.0	BUILDING C	36,000	15.5	230	1	17.6	30	177	<div><div>F</div><div>2.1</div></div>	<div><div>1</div><div>M4.01</div></div>	<div><div>3</div><div>M3.01</div></div>	1,2,3,4,5		
<div><div>F</div><div>C.3</div></div>	CARRIER 59SU5B080M21--20	BUILDING C	80,000	78,000	95	800	350	1.00	115	1	13.8	20	161	<div><div>EC</div><div>C.3</div></div>	<div><div>CU</div><div>C.3</div></div>	<div><div>1</div><div>M4.01</div></div>	<div><div>5</div><div>M3.01</div></div>	1,2,3,4,5,6,8,10,11	<div><div>CU</div><div>C.3</div></div>	CARRIER 26SCA536	3.0	BUILDING C	36,000	15.5	230	1	17.6	30	177	<div><div>F</div><div>2.2</div></div>	<div><div>1</div><div>M4.01</div></div>	<div><div>3</div><div>M3.01</div></div>	1,2,3,4,5		
<div><div>F</div><div>C.4</div></div>	CARRIER 59SU5B080M21--20	BUILDING C	80,000	78,000	95	800	355	1.00	115	1	13.8	20	161	<div><div>EC</div><div>C.4</div></div>	<div><div>CU</div><div>C.4</div></div>	<div><div>1</div><div>M4.01</div></div>	<div><div>5</div><div>M3.01</div></div>	1,2,3,4,5,6,8,10,11	<div><div>CU</div><div>C.4</div></div>	CARRIER 26SCA536	3.0	BUILDING C	36,000	15.5	230	1	17.6	30	177	<div><div>F</div><div>2.3</div></div>	<div><div>1</div><div>M4.01</div></div>	<div><div>3</div><div>M3.01</div></div>	1,2,3,4,5		
<div><div>F</div><div>C.5</div></div>	CARRIER 59SU5B080M21--20	BUILDING C	80,000	78,000	95	800	340	1.00	115	1	13.8	20	161	<div><div>EC</div><div>C.5</div></div>	<div><div>CU</div><div>C.5</div></div>	<div><div>1</div><div>M4.01</div></div>	<div><div>5</div><div>M3.01</div></div>	1,2,3,4,5,6,8,10,11	<div><div>CU</div><div>C.5</div></div>	CARRIER 26SCA536	3.0	BUILDING C	36,000	15.5	230	1	17.6	30	177	<div><div>F</div><div>3.1</div></div>	<div><div>1</div><div>M4.01</div></div>	<div><div>3</div><div>M3.01</div></div>	1,2,3,4,5		
<div><div>F</div><div>C.6</div></div>	CARRIER 59SU5B080M21--20	BUILDING C	80,000	78,000	95	800	340	1.00	115	1	13.8	20	161	<div><div>EC</div><div>C.6</div></div>	<div><div>CU</div><div>C.6</div></div>	<div><div>1</div><div>M4.01</div></div>	<div><div>5</div><div>M3.01</div></div>	1,2,3,4,5,6,8,10,11	<div><div>CU</div><div>C.6</div></div>	CARRIER 26SCA536	3.0	BUILDING C	36,000	15.5	230	1	17.6	30	177	<div><div>F</div><div>3.2</div></div>	<div><div>1</div><div>M4.01</div></div>	<div><div>3</div><div>M3.01</div></div>	1,2,3,4,5		
<div><div>F</div><div>D.1</div></div>	CARRIER 59SU5B080M21--20	BUILDING D	80,000	78,000	95	800	355	1.00	115	1	13.8	20	161	<div><div>EC</div><div>D.1</div></div>	<div><div>CU</div><div>D.1</div></div>	<div><div>1</div><div>M4.01</div></div>	<div><div>5</div><div>M3.01</div></div>	1,2,3,4,5,6,8,10,11	<div><div>CU</div><div>D.1</div></div>	CARRIER 26SCA536	3.0	BUILDING D	36,000	15.5	230	1	17.6	30	177	<div><div>F</div><div>3.3</div></div>	<div><div>1</div><div>M4.01</div></div>	<div><div>3</div><div>M3.01</div></div>	1,2,3,4,5		
<div><div>F</div><div>D.2</div></div>	CARRIER 59SU5B080M21--20	BUILDING D	80,000	78,000	95	1200	340	1.00	115	1	13.8	20	161	<div><div>EC</div><div>D.2</div></div>	<div><div>CU</div><div>D.2</div></div>	<div><div>1</div><div>M4.01</div></div>	<div><div>5</div><div>M3.01</div></div>	1,2,3,4,5,6,8,10,11	<div><div>CU</div><div>D.2</div></div>	CARRIER 26SCA536	3.0	BUILDING D	36,000	15.5	230	1	17.6	30	177	<div><div>F</div><div>7.1</div></div>	<div><div>1</div><div>M4.01</div></div>	<div><div>3</div><div>M3.01</div></div>	1,2,3,4,5		
<div><div>F</div><div>D.3</div></div>	CARRIER 59SU5B080M21--20	BUILDING D	80,000	78,000	95	1200	340	1.00	115	1	13.8	20	161	<div><div>EC</div><div>D.3</div></div>	<div><div>CU</div><div>D.3</div></div>	<div><div>1</div><div>M4.01</div></div>	<div><div>5</div><div>M3.01</div></div>	1,2,3,4,5,6,8,10,11	<div><div>CU</div><div>D.3</div></div>	CARRIER 26SCA536	3.0	BUILDING D	36,000	15.5	230	1	17.6	30	177	<div><div>F</div><div>7.2</div></div>	<div><div>1</div><div>M4.01</div></div>	<div><div>3</div><div>M3.01</div></div>	1,2,3,4,5		
<div><div>F</div><div>D.4</div></div>	CARRIER 59SU5B080M21--20	BUILDING D	80,000	78,000	95	1200	350	1.00	115	1	13.8	20	161	<div><div>EC</div><div>D.4</div></div>	<div><div>CU</div><div>D.4</div></div>	<div><div>1</div><div>M4.01</div></div>	<div><div>5</div><div>M3.01</div></div>	1,2,3,4,5,6,8,10,11	<div><div>CU</div><div>D.4</div></div>	CARRIER 26SCA536	3.0	BUILDING D	36,000	15.5	230	1	17.6	30	177	<div><div>F</div><div>7.3</div></div>	<div><div>1</div><div>M4.01</div></div>	<div><div>3</div><div>M3.01</div></div>	1,2,3,4,5		
<div><div>F</div><div>D.5</div></div>	CARRIER 59SU5B080M21--20	BUILDING D	80,000	78,000	95	1200	350	1.00	115	1	13.8	20	161	<div><div>EC</div><div>D.5</div></div>	<div><div>CU</div><div>D.5</div></div>	<div><div>1</div><div>M4.01</div></div>	<div><div>5</div><div>M3.01</div></div>	1,2,3,4,5,6,8,10,11	<div><div>CU</div><div>D.5</div></div>	CARRIER 26SCA536	3.0	BUILDING D	36,000	15.5	230	1	17.6	30	177	<div><div>F</div><div>8.1</div></div>	<div><div>1</div><div>M4.01</div></div>	<div><div>3</div><div>M3.01</div></div>	1,2,3,4,5		
<div><div>F</div><div>D.6</div></div>	CARRIER 59SU5B080M21--20	BUILDING D	80,000	78,000	95	800	345	1.00	115	1	13.8	20	161	<div><div>EC</div><div>D.6</div></div>	<div><div>CU</div><div>D.6</div></div>	<div><div>1</div><div>M4.01</div></div>	<div><div>5</div><div>M3.01</div></div>	1,2,3,4,5,6,8,10,11	<div><div>CU</div><div>D.6</div></div>	CARRIER 26SCA536	3.0	BUILDING D	36,000	15.5	230	1	17.6	30	177	<div><div>F</div><div>8.2</div></div>	<div><div>1</div><div>M4.01</div></div>	<div><div>3</div><div>M3.01</div></div>	1,2,3,4,5		
<div><div>F</div><div>E.1</div></div>	CARRIER 58SU5B100M21--22	BUILDING E	100,000	97,000	95	1720	1005	1.50	115	1	13.8	20	170	<div><div>EC</div><div>E.1</div></div>	<div><div>CU</div><div>E.1</div></div>	<div><div>1</div><div>M4.01</div></div>	<div><div>4</div><div>M3.01</div></div>	1,2,3,4,5,6,8,10,11	<div><div>CU</div><div>E.1</div></div>	CARRIER 26SCA560	5.0	BUILDING E	60,000	15.0	230	1	31.4	50	216	<div><div>F</div><div>8.3</div></div>	<div><div>1</div><div>M4.01</div></div>	<div><div>3</div><div>M3.01</div></div>	1,2,3,4,5		
<div><div>F</div><div>E.2</div></div>	CARRIER 58SU5B100M21--22	BUILDING E	100,000	97,000	95	1720	1005	1.50	115	1	13.8	20	170	<div><div>EC</div><div>E.2</div></div>	<div><div>CU</div><div>E.2</div></div>	<div><div>1</div><div>M4.01</div></div>	<div><div>4</div><div>M3.01</div></div>	1,2,3,4,5,6,8,10,11	<div><div>CU</div><div>E.2</div></div>	CARRIER 26SCA560	5.0	BUILDING E	60,000	15.0	230	1	31.4	50	216	<div><div>F</div><div>9.1</div></div>	<div><div>1</div><div>M4.01</div></div>	<div><div>3</div><div>M3.01</div></div>	1,2,3,4,5		
<div><div>F</div><div>E.3</div></div>	CARRIER 59SU5B080M21--20	BUILDING E	80,000	78,000	95	800	325	1.20	115	1	13.8	20	161	<div><div>EC</div><div>E.3</div></div>	<div><div>CU</div><div>E.3</div></div>	<div><div>1</div><div>M4.01</div></div>	<div><div>4</div><div>M3.01</div></div>	1,2,3,4,5,6,8,10,11	<div><div>CU</div><div>E.3</div></div>	CARRIER 26SCA536	3.0	BUILDING E	36,000	15.5	230	1	17.6	30	177	<div><div>F</div><div>9.2</div></div>	<div><div>1</div><div>M4.01</div></div>	<div><div>3</div><div>M3.01</div></div>	1,2,3,4,5		

1. PROVIDE ULTRA LOW NOX UNIT AND INSTALL NEW UPFLOW FURNACE UNIT PER MANUFACTURER INSTRUCTIONS.
2. ALL DIMENSIONS, SERVICE ACCESS LOCATIONS, AND CONNECTION LOCATIONS SHALL BE FIELD VERIFIED PRIOR TO ORDERING.
3. UNIT CAPACITIES ARE BASED ON OUTDOOR DESIGN TEMPERATURES OF 78 DEG F DB/62 DEG F WB DURING COOLING PERIOD AND 34 DEG F DB DURING HEATING PERIOD.
4. ELECTRO-MECHANICAL CONTROL FOR ALERTON CONTROL INTERFACE.
5. PROVIDE SOUTHWARK METAL MFG. CO FURNACE FILTER BASE (GFFB62025 OR APPROVED EQUAL) W/ 1" THICK 267253 MERV 13 FILTER. ASHRAE COMPLIANT @ 85% EFFICIENCY(PARTICLE SIZE 1.0-3.0 MICRONS). PROVIDE PAMILCO AIR FILTER MODEL PRIME13 OR APPROVED EQUAL @ 0.11 MAX. PD IN. WG FOR 3-TON & 0.2 PD IN. WG. FOR 5-TON). SEE FLOOR PLAN FOR FILTER ORIENTATION.
6. PROVIDE CONCENTRIC VENT KIT (3")
7. PROVIDE SOUTHWARK METAL MFG. CO FURNACE FILTER BASE (GFFB41625 OR APPROVED EQUAL) W/ 2" THICK 167253 MERV 13 FILTER. ASHRAE COMPLIANT @ 85% EFFICIENCY(PARTICLE SIZE 1.0-3.0 MICRONS). PROVIDE PAMILCO AIR FILTER MODEL PRIME13 OR APPROVED EQUAL @ 0.24 MAX. PD IN. WG FOR 3-TON). SEE FLOOR PLAN FOR FILTER ORIENTATION.
8. PROVIDE ULTRA LOW NOX UNIT WITH FACTORY SUPPLIED CONDENSATE NEUTRALIZER KIT.
9. PROVIDE CONDENSATE TRAP OFFSET ADAPTER KIT - UPFLOW WITH RIGHT SIDE RETURN
10. PROVIDE DEMAND CONTROL VENTILATION
11. PROVIDE COASTAL CORROSION PROTECTION. FULLY COAT EXTERIOR AND INTERIOR OF CABINET. INSTITUTE SPRAY COAT ES[®] BY GORILLA COATINGS OR APPROVED EQUAL.

NOTE:

1. ALL DIMENSIONS, SERVICE FURNACE ACCESS LOCATIONS, AND CONNECTION LOCATIONS SHALL BE VERIFIED PRIOR TO ORDERING/BEGINNING INSTALLATION. CONTRACTOR TO PROVIDE FILTER BOX LAYOUT WITH FURNACE IN SHOP DRAWINGS.
2. INSTALLING CONTRACTOR TO PROVIDE LIQUID & GAS LINE REFRIGERANT PIPES AS PER BELOW:
 - 3-TON :3/8" LIQUID LINE & 7/8" GAS LINE.
 - 5-TON :3/8" LIQUID LINE & 1-1/8" GAS LINE.

- REMARKS:
1. PROVIDE AND INSTALL NEW CONDENSING UNIT PER MANUFACTURER INSTRUCTIONS.
 2. PROVIDE NEOPRENE PADS.
 3. UNIT CAPACITIES ARE BASED ON OUTDOOR DESIGN TEMPERATURES OF 78 DE F DB
COOLING PERIOD 14.34 DE F DB DURING HEATING PERIOD.
 4. INSULATE REFRIGERANT PIPING LINES IN ITS ENTIRETY FROM OUTDOOR UNIT TO INDOR.
 5. PROVIDE ALUMINUM WEATHER JACKETING FOR ALL OUTDOOR REFRIGERANT PIPING.
 6. PROVIDE COASTAL CORROSION PROTECTION. FULLY COAT THE EXTERIOR AND INTER COILS. INSTITUTE SPRAY COAT ES² BY GORILLA COATINGS OR APPROVED EQUAL.
 7. TYPE R-454B REFRIGERANT.
 8. INSTALL FILTER DRIERS INDOORS AND ADJACENT TO COILS.

NOTE:

1. REFRIGERANT LINE SIZES ARE 3/8" RL & 7/8" RG FOR 3-TON UNIT AND 3/8" RL & 1-1/8" FOR 5-TON UNITS. CONTRACTOR SHALL COORDINATE FINAL REFRIGERANT PIPE SIZES WITH MANUFACTURER REPRESENTATIVE BASED UPON DETERMINATION OF ACTUAL IN FIELD DEVELOPED LENGTH PRIOR TO ORDERING PRODUCT.


EVAPORATOR COIL SCHEDULE - BUILDINGS A, B, C, D, E										
SYM	MFR & MODEL #	AREA SERVICED	COOLING CAP.(BTUH)	CFM	APD (IN WG)	WT (LBS)	INTERLOCK WITH	CONTROL DETAIL	ANCHORAGE DETAIL	REMARKS
	CARRIER CAAMP6024AMA	BUILDING A	60,000	1645	0.24	92				1,2,3,4,6,7
	CARRIER CAAMP3617AMA	BUILDING B	36,000	1200	0.17	67				1,2,3,4,5,6,7
	CARRIER CAAMP3617AMA	BUILDING B	36,000	1200	0.17	67				1,2,3,4,5,6,7
	CARRIER CAAMP3617AMA	BUILDING C	36,000	1200	0.17	67				1,2,3,4,5,6,7
	CARRIER CAAMP3617AMA	BUILDING C	36,000	1200	0.17	67				1,2,3,4,5,6,7
	CARRIER CAAMP3617AMA	BUILDING C	36,000	800	0.17	67				1,2,3,4,5,6,7
	CARRIER CAAMP3617AMA	BUILDING C	36,000	800	0.17	67				1,2,3,4,5,6,7
	CARRIER CAAMP3617AMA	BUILDING C	36,000	800	0.17	67				1,2,3,4,5,6,7
	CARRIER CAAMP3617AMA	BUILDING C	36,000	800	0.17	67				1,2,3,4,5,6,7
	CARRIER CAAMP3617AMA	BUILDING D	36,000	800	0.17	67				1,2,3,4,5,6,7
	CARRIER CAAMP3617AMA	BUILDING D	36,000	1200	0.17	67				1,2,3,4,5,6,7
	CARRIER CAAMP3617AMA	BUILDING D	36,000	1200	0.17	67				1,2,3,4,5,6,7
	CARRIER CAAMP3617AMA	BUILDING D	36,000	1200	0.17	67				1,2,3,4,5,6,7
	CARRIER CAAMP3617AMA	BUILDING D	36,000	1200	0.17	67				1,2,3,4,5,6,7
	CARRIER CAAMP3617AMA	BUILDING D	36,000	800	0.17	67				1,2,3,4,5,6,7
	CARRIER CAAMP6024AMA	BUILDING E	60,000	1720	0.24	92				1,2,3,4,6,7
	CARRIER CAAMP6024AMA	BUILDING E	60,000	1720	0.24	92				1,2,3,4,6,7
	CARRIER CAAMP3617AMA	BUILDING E	36,000	800	0.17	67				1,2,3,4,6,7

1. PROVIDE AND INSTALL NEW EVAPORATIVE COIL UNIT PER MANUFACTURER INSTRUCTIONS.
2. ALL DIMENSIONS, SERVICE ACCESS LOCATIONS, AND CONNECTION LOCATIONS SHALL BE FIELD DETERMINED PRIOR TO ORDERING.
3. INSTALL FILTER DRIERS IDEOS ADJACENT TO COILS. PROVIDE PIPE INSULATION FOR ALL REFRIGERANT AND CONDENSATE DRAIN PIPING.
4. TYPE R454B REFRIGERANT.
5. PROVIDE CONDENSATE PUMP AND RE-CONNECT EXISTING POWER.
6. R454B LEAK DISSIPATION SYSTEM FURNISHED BY FACTORY AND FIELD INSTALLED BY CONTRACTOR
7. PROVIDE COASTAL CORROSION PROTECTION, FULLY COAT THE EXTERIOR AND INTERIOR OF CABINE INCLUDING COILS. INSTITUTE SPRAY COAT ES[®] BY GORILLA COATINGS OR APPROVED EQUAL.

PIPE MATERIAL SCHEDULE												
SERVICE	LOCATION	<div>MATERIAL COPPER PIPE COPPER PIPE TYPE "C" COPPER PIPE TYPE "M" BLACK STEEL SCH 40 POLYETHYLENE PIPE TYPE & THICKS NO HUB CAST IRON HUB AND SPIGOT CAST IRON</div>										REMARKS
NATURAL GAS (NG)	ABOVE GROUND				●						2	
CONDENSATE DRAINAGE (CD)	ABOVE GROUND			●							1.3	

- REMARKS:
1. PROVIDE INDOOR CONDENSATE PIPING WITH INSULATION BY "LMCOA" "LMCOLOCK": 3/4" THICKNESS CLOSED-CELL INSULATION. INSULATION SHALL HAVE A FLAME SPREAD OF NOT MORE THAN 25 AND A SMOKE DENSITY NOT EXCEEDING 50 PER 2022 CMC. ALL JOINTS SHALL BE MITERED AND SECURED WITH BLACK DUCT TAPE.
 2. HPIPE/DISCHARGE SCHEDULE 40 BLACK STEEL CONFORMING TO ASTM A53 WITH BLACK MALLEABLE IRON THREADED FITTINGS CONFORM TO ASME B16.3 FOR PIPING 2 INCHES AND SMALLER ABOVE GROUND.
 3. PROVIDE ASTM B 88, TYPE M COPPER PIPE FOR ABOVE GROUND.

AIR DISTRIBUTION SCHEDULE									
SYM.	MFR. & MODEL #	NECK SIZE	CFM RANGE	MAX. NECK VELOCITY	MAX. N.C.	S.P. DROP	TYPE	DAMPER	REMARKS
	KRUEGER EGC5	24"X24"	0-1400	400	30	.03	EGG-CRATE	NONE	FRAME 23 FOR T-BAR

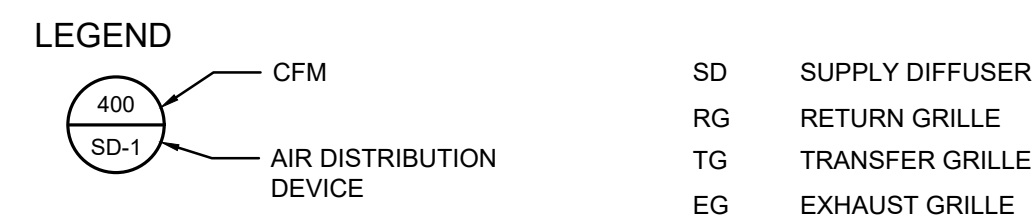

GRAVITY HOOD SCHEDULE									
SYM.	MFR & MODEL#	TYPE	CFM	PD	THROAT SIZE	FREE AREA	HOOD SIZE (W x L)	WT	REMARKS
 GR A.1	GREENHECK FGR	RELIEF	975	.05	18"x18"	2.25 SQ.FT.	32"x39"	75 LBS	1, 2, 3
 GR A.2	GREENHECK FGR	RELIEF	670	.05	18"x18"	2.25 SQ.FT.	32"x39"	75 LBS	1, 2, 3
 GI A.3	GREENHECK FGI	INTAKE	1645	.03	24"x24"	4.0 SQ.FT.	52"x39"	90 LBS	1, 2, 3
 GR B.1	GREENHECK FGR	RELIEF	1200	.05	14"x30"	2.92 SQ.FT.	28"x51"	75 LBS	2, 3, 4
 GR B.2	GREENHECK FGR	RELIEF	1200	.05	14"x30"	2.92 SQ.FT.	28"x51"	75 LBS	1, 2, 3
 GR C.1	GREENHECK FGR	RELIEF	1200	.05	20"x20"	2.78 SQ.FT.	34"x39"	75 LBS	1, 2, 3
 GR C.2	GREENHECK FGR	RELIEF	1200	.05	20"x20"	2.78 SQ.FT.	34"x39"	75 LBS	1, 2, 3
 GR D.2	GREENHECK FGR	RELIEF	1200	.05	20"x20"	2.78 SQ.FT.	34"x39"	75 LBS	1, 2, 3
 GR D.3	GREENHECK FGR	RELIEF	1200	.05	20"x20"	2.78 SQ.FT.	34"x39"	75 LBS	1, 2, 3
 GR D.4	GREENHECK FGR	RELIEF	1200	.05	20"x20"	2.78 SQ.FT.	34"x39"	75 LBS	1, 2, 3
 GR D.5	GREENHECK FGR	RELIEF	1200	.05	20"x20"	2.78 SQ.FT.	34"x39"	75 LBS	1, 2, 3

- REMARKS:
1. PROVIDE GREENHECK WD-100 COUNTERBALANCE DAMPER PER THE THROAT SIZE
 2. PROVIDE INSECT SCREEN.
 3. PROVIDE 14" ROOF CURB.
 4. PROVIDE MOTORIZED DAMPER PER M4.01, EMS CONTROL DIAGRAMS.



Consulting Engineers
5277 College Avenue
Oakland, CA 94618
Telephone (510) 837-9182

This document is the property of the Owner and is not to be used without their written permission



HY Architects Project number:	Project Number
-------------------------------	----------------

Facility	SKYLINE ELEMENTARY SCHOOL 55 CHRISTEN AVE, DALY CITY, CA 94015
----------	---

Project

HVAC REPLACEMENT

Sheet Title

MECHANICAL SCHEDULES

Client Project Number: 0000.0

Scale: Not to Scale

Drawn By: CC

Checked B




Issue Date:

Sheet

M0.03

Sheet of

3/20/2023 3:12:50 PM M:\P - PROJECTS\2025\002-25-0001 SFUSD SKYLINE ES\02_MECH

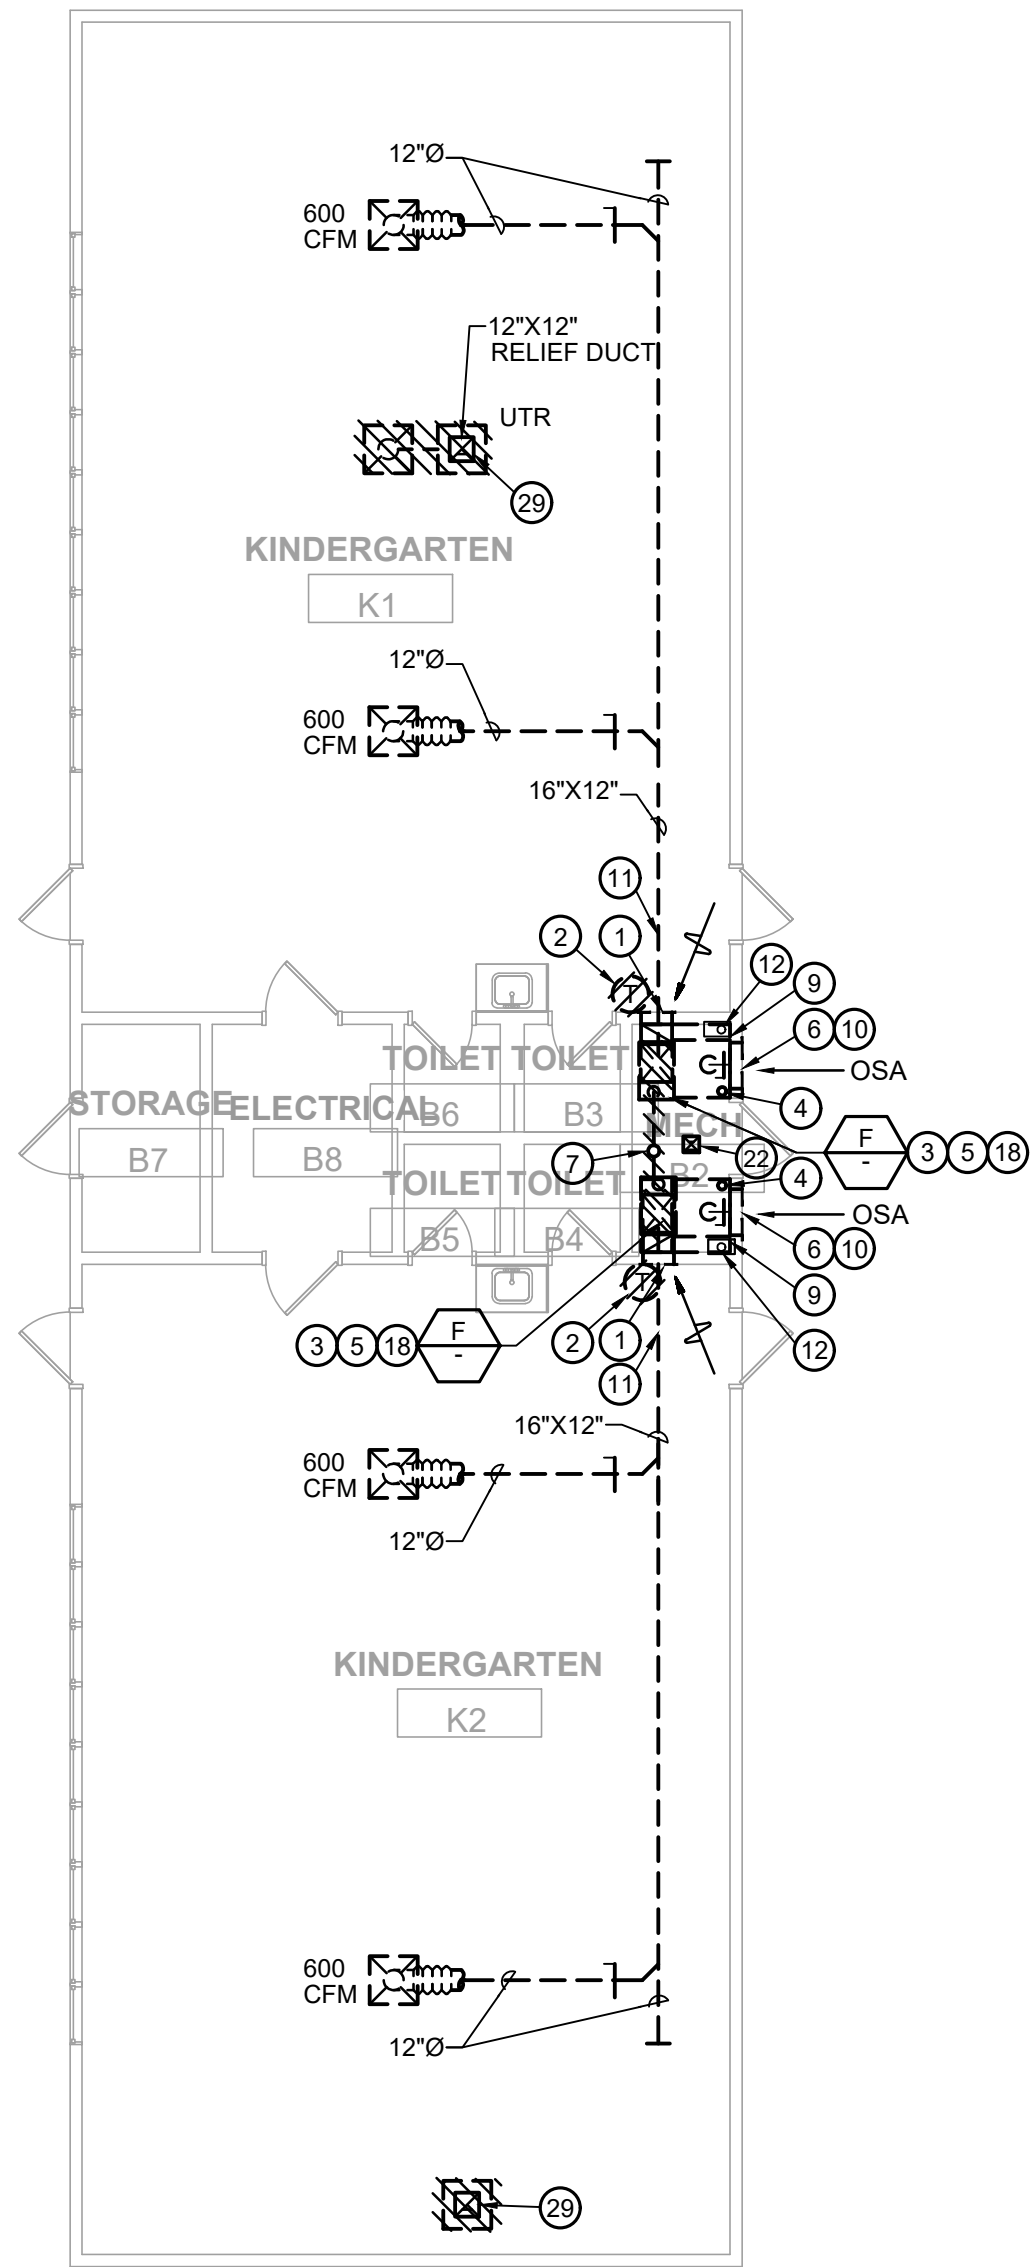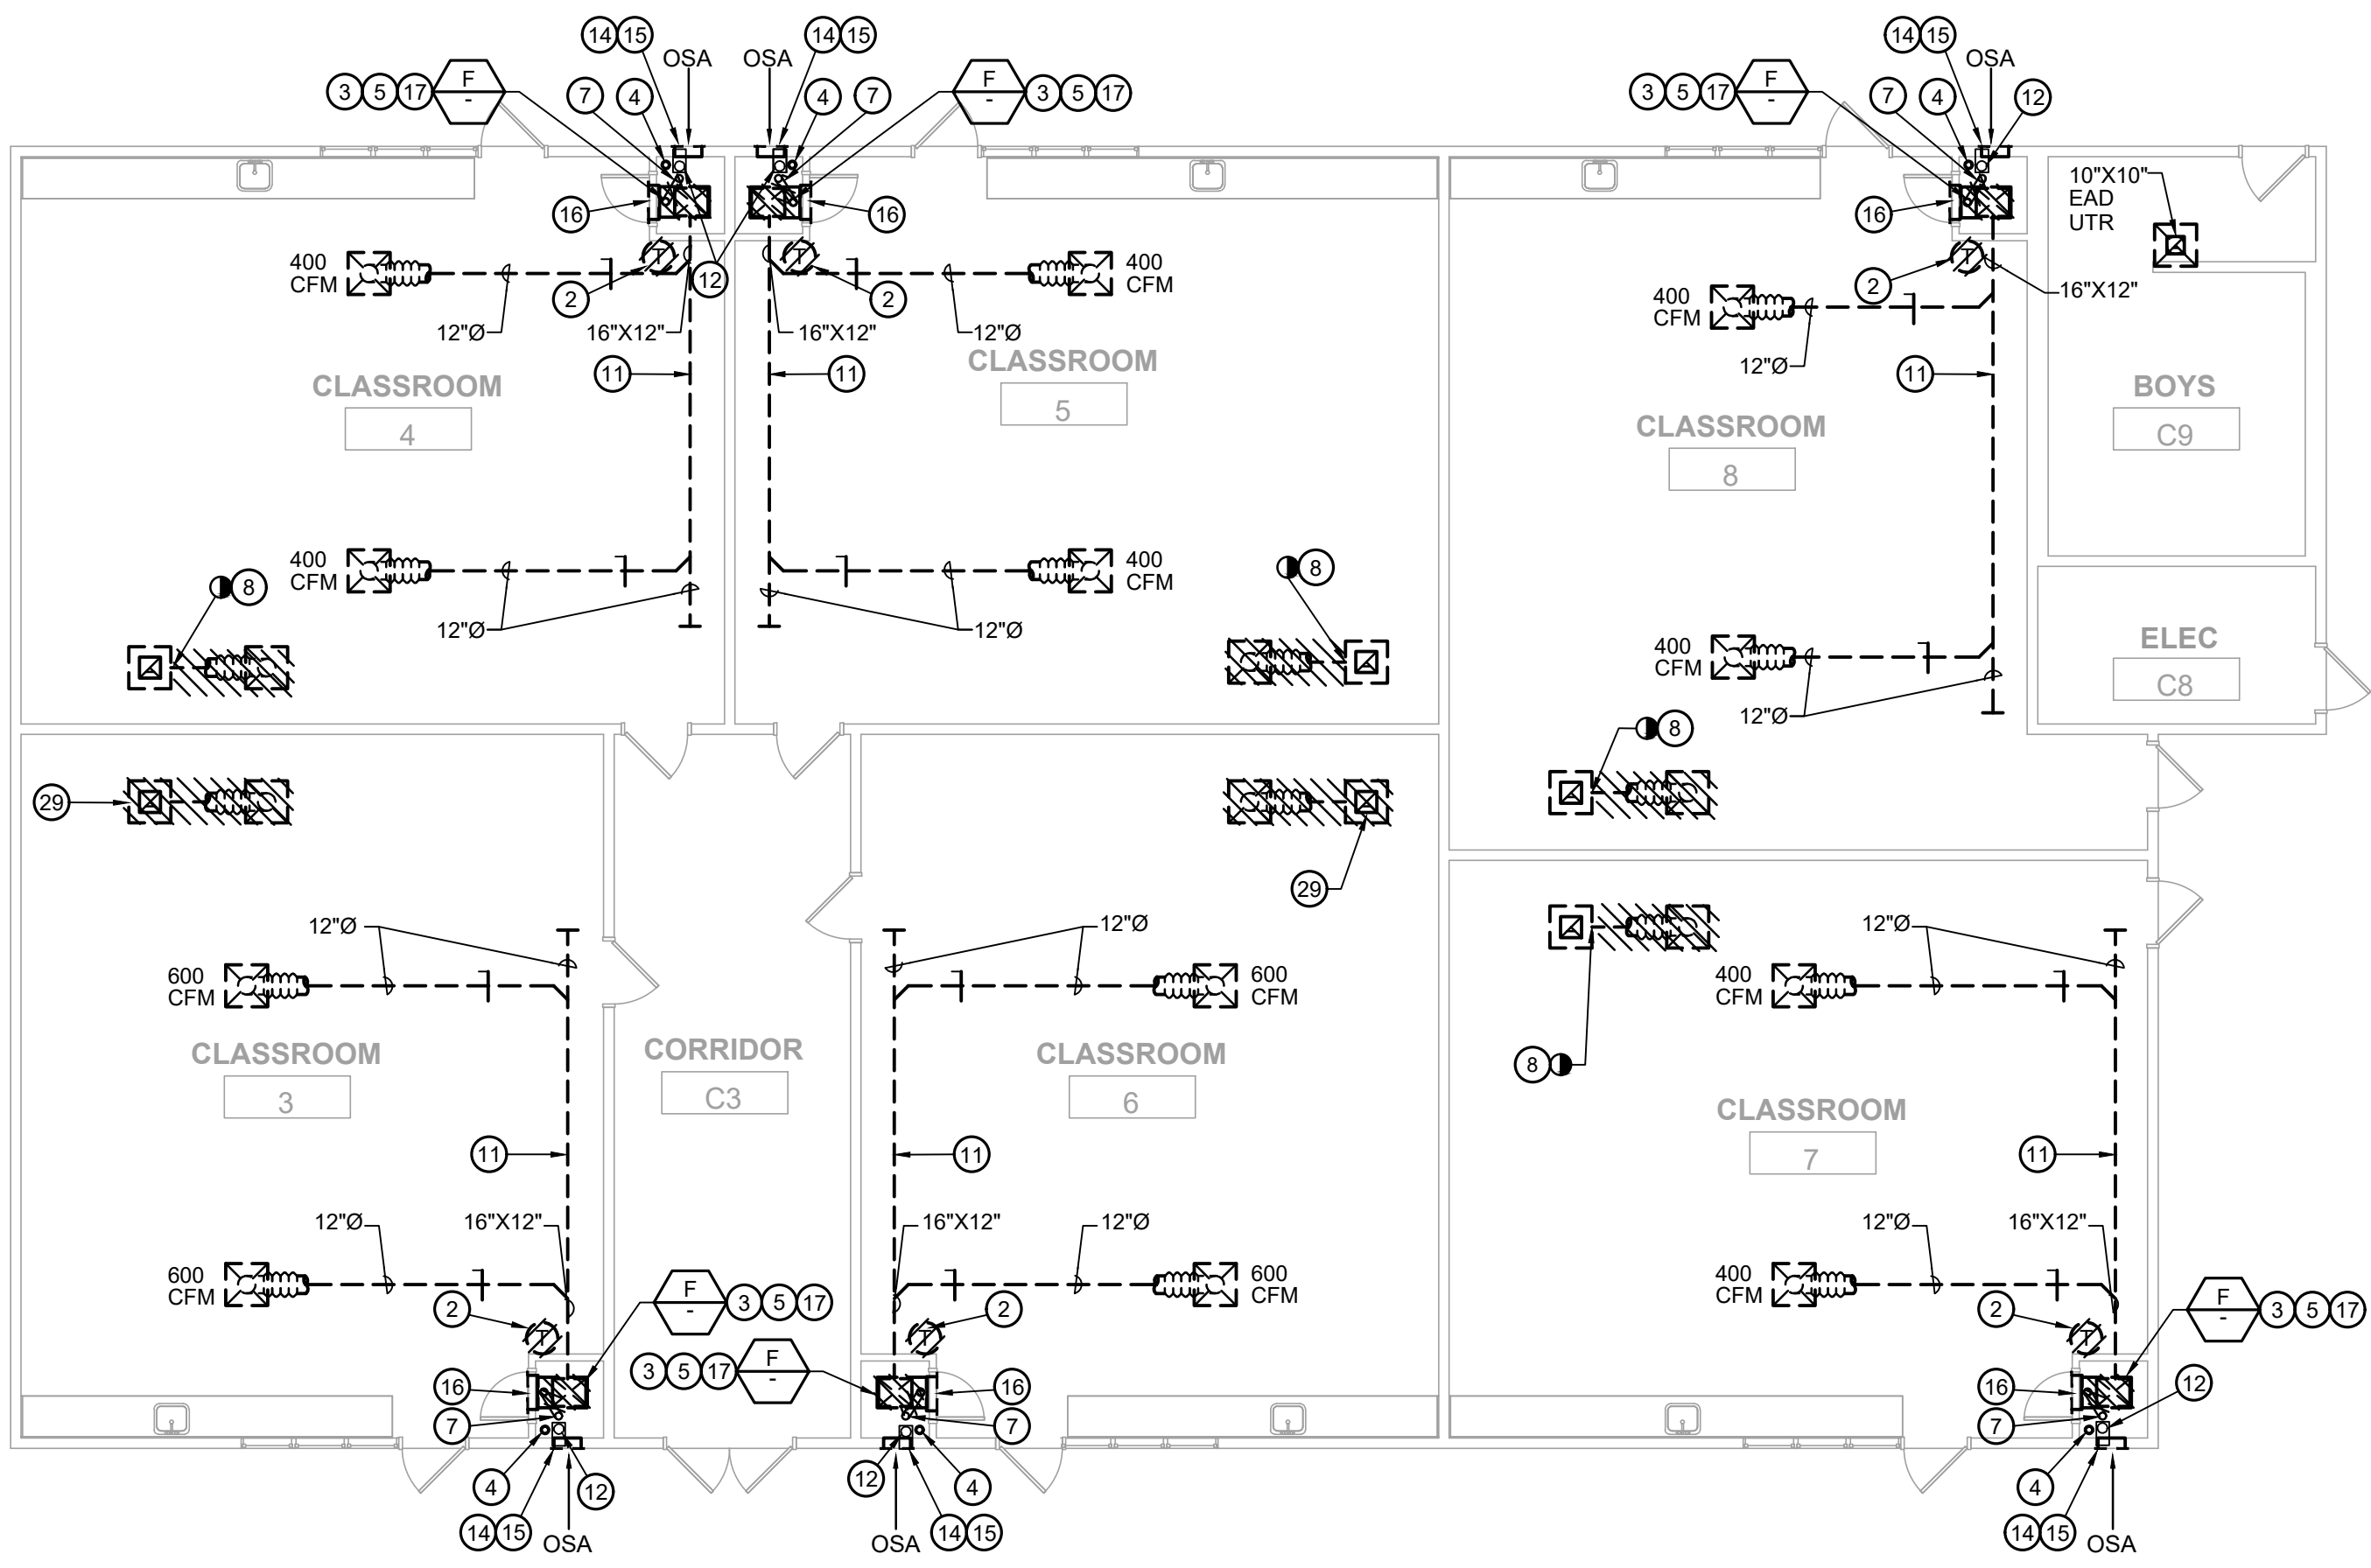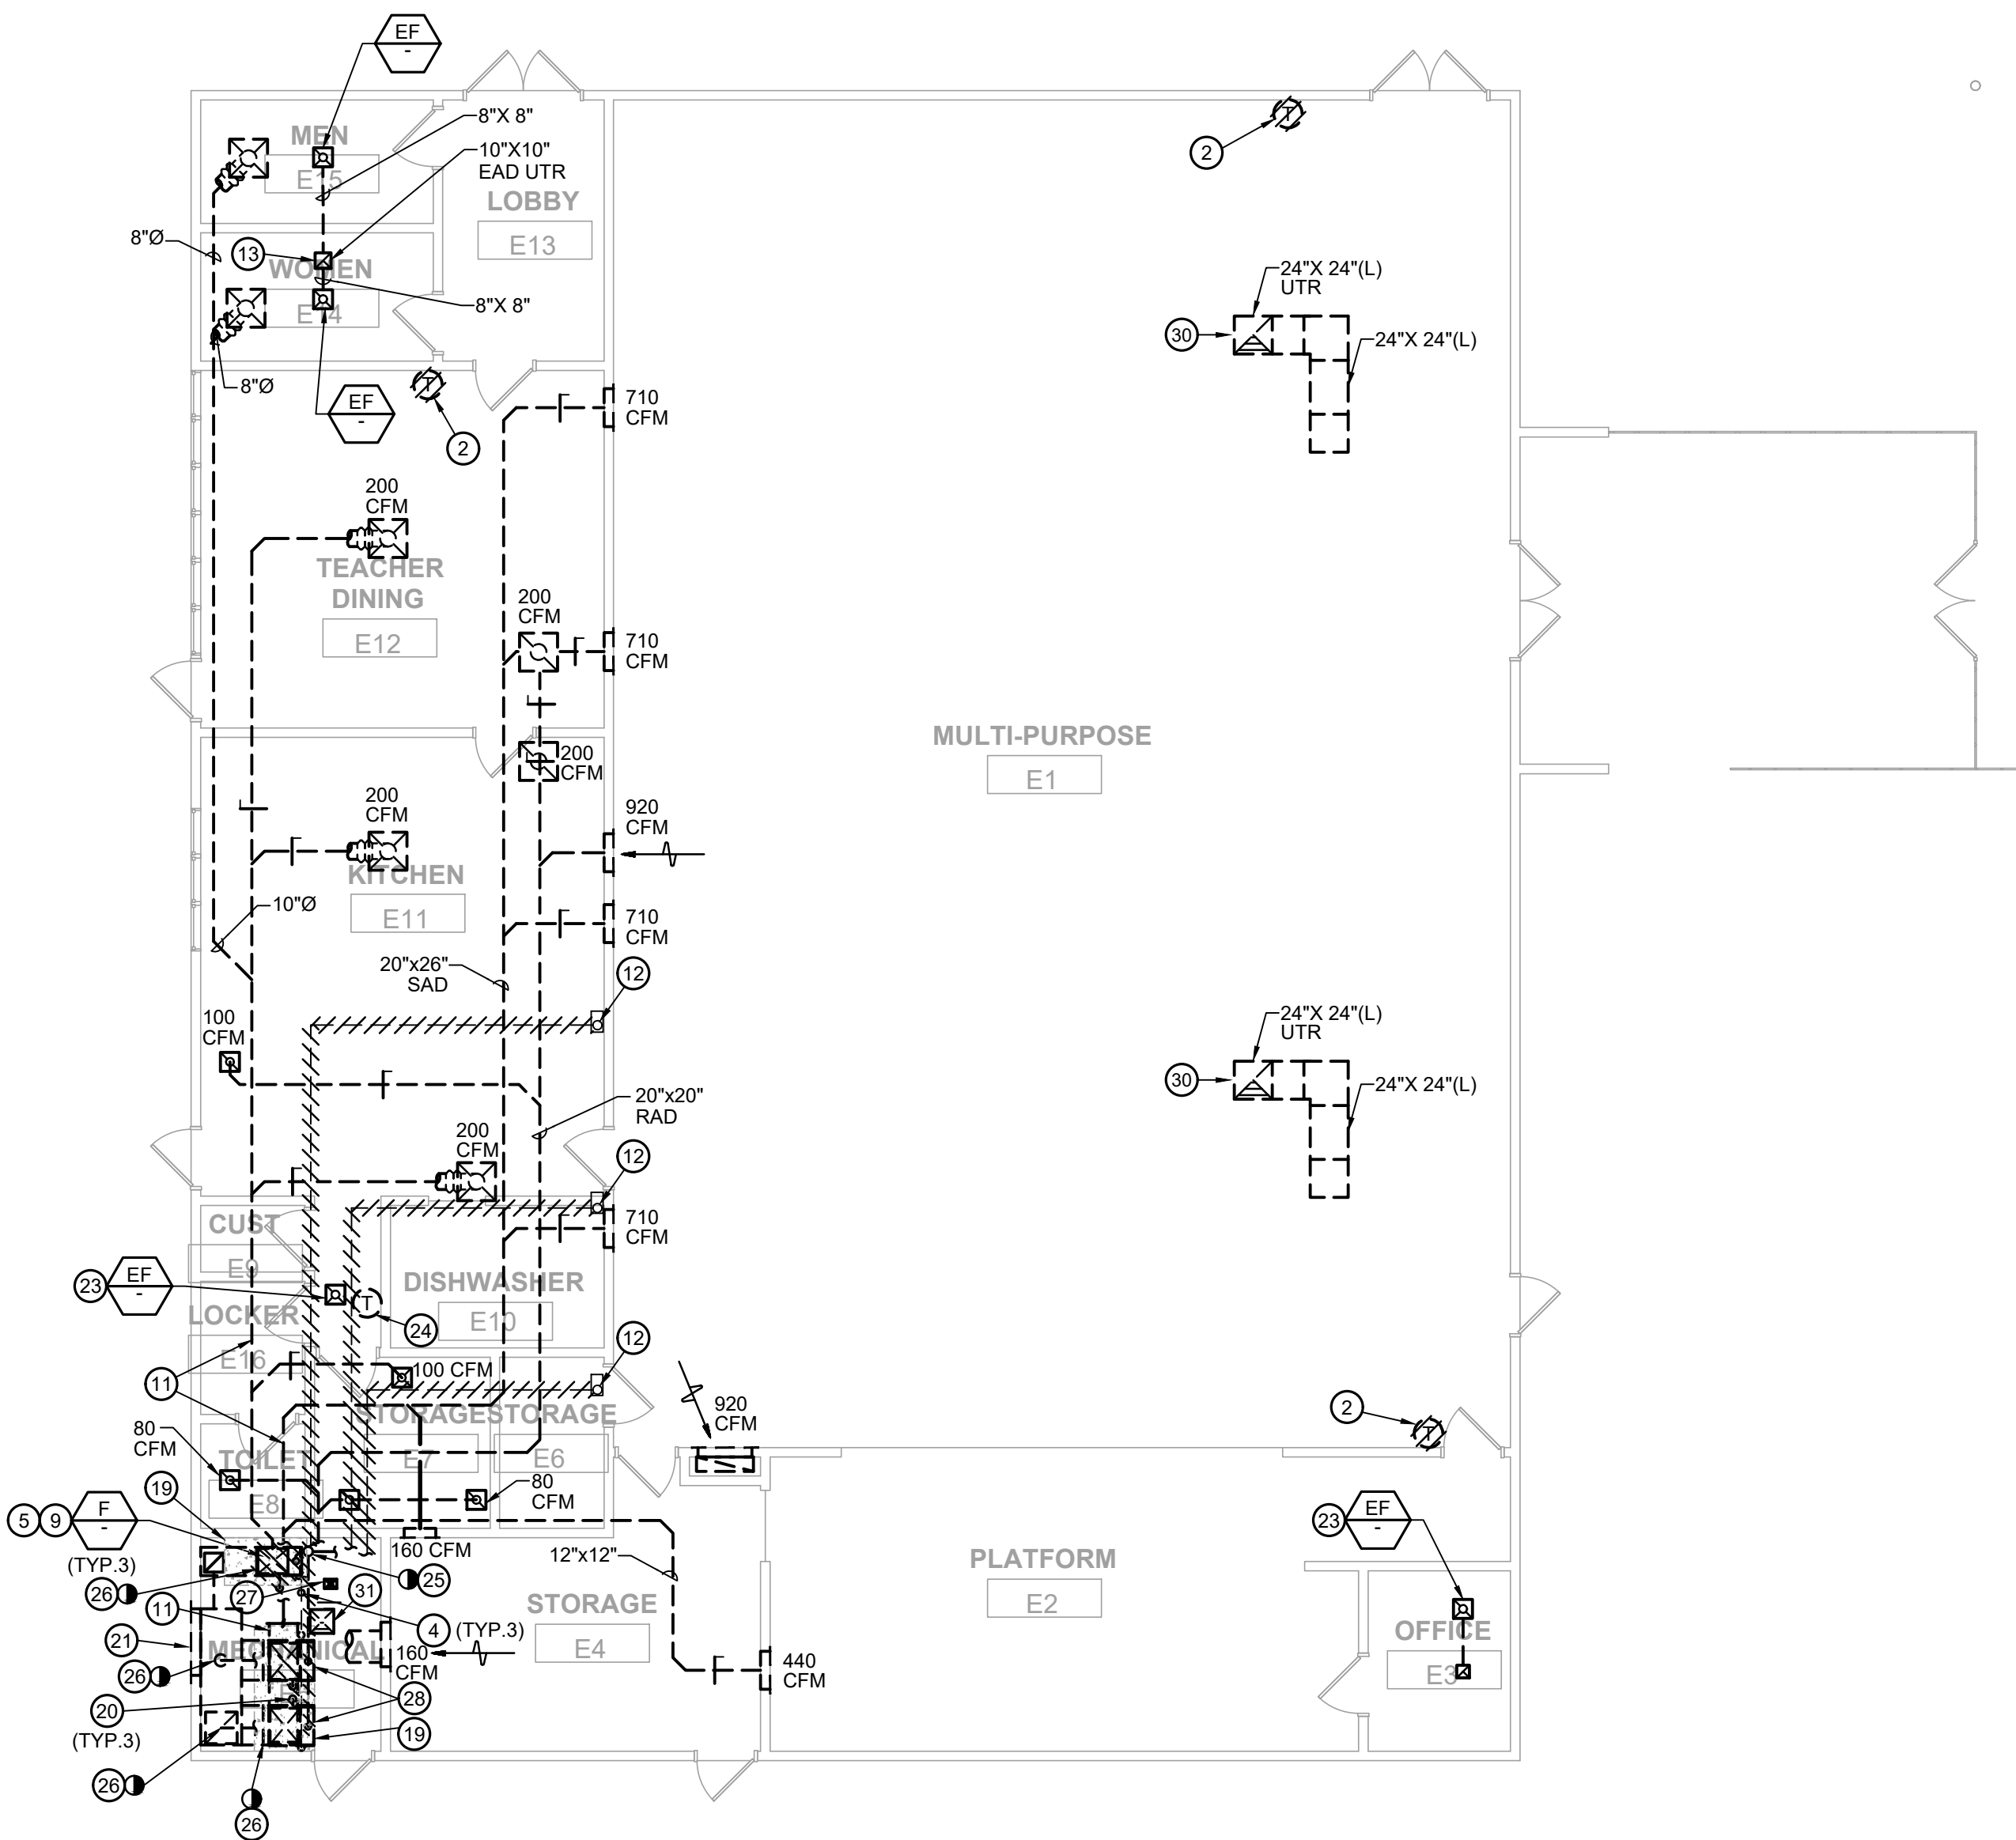


DEMOLITION CONSTRUCTION NOTES:

- CONTRACTOR SHALL REUSE EXISTING OPENING(S) IN WALLS AND/OR ROOF FOR FUTURE PIPING AND ETC WHEREVER POSSIBLE. COORDINATE WITH OTHER TRADES AS NECESSARY.
- CONTRACTOR SHALL PATCH AND REPAIR EXISTING WALLS, FLOORS, CEILINGS, AND/OR ROOF OPENING(S) AS NECESSARY FOR EXISTING HVAC EQUIPMENT, DUCTS, PIPING, & ETC, BEING REMOVED AND/OR MODIFIED. MATCH SURROUNDING MATERIAL AND MAINTAIN FIRE RATING.
- EXISTING EXTERIOR WALL LOUVERS ARE BEING REPLACED WITH NEW BY ARCHITECTURAL. SEE ARCHITECTURAL DRAWINGS FOR ADDITIONAL INFORMATION.
- REMOVE EXISTING DDC CONTROLLERS FROM ASSOCIATED EXISTING FURNACES AND SPLIT SYSTEMS BEING REMOVED. CONTRACTOR SHALL FIELD VERIFY THEIR LOCATIONS. INSTALL UNITARY CONTROLLERS FOR NEW WORK.
- PROVIDE SS CONSTRUCTED COUNTERBALANCE BACKDRAFT DAMPERS FOR ALL BLDGS. RELIEF AIR HOODS. FURNISHED AND INSTALLED BY MECHANICAL CONTRACTOR.
- REPLACE EXISTING DDC CONTROLLERS WITH NEW INCLUDING ACTUATORS AND OSARA DAMPERS FOR ALL BUILDINGS. INSTALL SS CONSTRUCTED DAMPERS INCLUDING LINKAGES BY MECHANICAL. 24V MOTORIZED DAMPER ACTUATORS BY CONTROL CONTRACTOR.
- NO WALL OPENINGS ARE PERMITTED WITHOUT SEOR APPROVAL. EXCEPT RE-USING EXISTING OPENINGS AND MODIFICATION TO EXISTING OPENINGS AS NOTED ON THESE PLANS AND DETAILS ON STRUCTURAL DRAWING SS.01.


DEMOLITION KEY NOTES:

- RETAIN EXISTING RETURN AIR GRILLE.
- REMOVE EXISTING FURNACE THERMOSTAT.
- REMOVE EXISTING COOLING COIL CONDENSATE PIPING IN ITS ENTIRETY INCLUDING CONDENSATE PUMP. RETAIN EXISTING POWER FOR NEW WORK.
- DISCONNECT EXISTING NG PIPING FROM FURNACE. RETAIN EXISTING NG SUPPLY PIPING FOR NEW WORK RE-CONNECTION.
- REMOVE EXISTING GAS FIRED FURNACE AND ASSOCIATED APPURTENANCES INCLUDING BUT NOT LIMITED TO CONTROL, SUPPORTS, AND COOLING COIL. SEE ELECTRICAL DRAWINGS FOR ADDITIONAL INFORMATION.
- EXISTING HIGH WALL MOUNTED OSA EXTERIOR LOUVER SHALL BE REPLACED WITH NEW BY ARCHITECTURAL. DEMOLISH EXISTING OSA DUCT FROM LOUVER TO MIXING BOX.
- REMOVE EXISTING FLUE PIPING AND RISER UP THRU' ROOF FROM EXISTING FURNACE(S).
- REMOVE EXISTING RELIEF AIR DUCT UP THRU' ROOF FROM ROOFTOP RELIEF AIR GRAVITY HOOD TO REMAIN.
- DEMOLISH EXISTING AIR MIXING BOX.
- EXISTING LOW WALL MOUNTED COMBUSTION AIR EXTERIOR LOUVER SHALL BE REPLACED WITH NEW BY ARCHITECTURAL.
- EXISTING SUPPLY AIR DISTRIBUTION TO REMAIN. DISCONNECT DUCT FROM EXISTING FURNACE(S) TO BE REMOVED AND RECONNECT AT NEW WORK INSTALLATION.
- DEMOLISH EXISTING SPLIT SYSTEM REFRIGERANT PIPING (RG & RL) IN ITS ENTIRETY.
- EXISTING EXHAUST AIR DUCT UP THRU' ROOF TO ROOFTOP EXHAUST AIR FAN TO REMAIN.
- EXISTING LOW WALL MOUNTED OSA EXTERIOR LOUVER AT AIR MIXING BOX SHALL BE REPLACED WITH NEW BY ARCHITECTURAL.
- EXISTING HIGH WALL MOUNTED COMBUSTION AIR EXTERIOR LOUVER SHALL BE REPLACED WITH NEW BY ARCHITECTURAL. DEMOLISH EXISTING ASSOCIATED DUCTWORK.
- RETAIN EXISTING RETURN AIR GRILLE AT AIR MIXING BOX.
- EXISTING FURNACE CLOSET AND AIR MIXING BOX SHALL REMAIN FULLY INTACT BY CONTRACTOR. REPLACE EXISTING LINING WITH NEW AND REMOVE FILTER RACK AT TOP OF AIR MIXING BOX. SEE ARCHITECTURAL DRAWINGS FOR ADDITIONAL INFORMATION.
- EXISTING EQUIPMENT PLATFORM SHALL REMAIN FULLY INTACT BY CONTRACTOR.
- EXISTING CONCRETE PAD TO REMAIN.
- REMOVE EXISTING COOLING COIL CONDENSATE PIPING IN ITS ENTIRETY.
- EXISTING EXTERIOR WALL AIR LOUVER SHALL BE REPLACED WITH NEW BY ARCHITECTURAL. DEMOLISH EXISTING OSA AIR PLENUM AND ASSOCIATED DUCTWORK FROM FURNACES.
- EXISTING COMBUSTION AIR DUCT UP THRU' ROOF TO ROOFTOP GRAVITY HOOD TO REMAIN. ABANDON IN PLACE.
- EXISTING EXHAUST FAN TO REMAIN.
- EXISTING THERMOSTAT FOR EXHAUST FAN TO REMAIN.
- EXISTING FLUE UP THRU' ROOF TO REMAIN. REMOVE EXISTING FLUE FROM EXISTING FURNACE(S) BEING REMOVED AND CUT AND CAP FLUE AT POD.
- RETAIN EXISTING RETURN AIR DISTRIBUTION FOR RE-CONNECTION AT NEW WORK INSTALLATION.
- EXISTING FLOOR DRAIN.
- REMOVE AND RE-INSTALL EXISTING DUCT MOUNTED SMOKE DETECTOR AS REQUIRED.
- DEMOLISH EXISTING RELIEF AIR DUCT UP THRU' ROOF TO EXISTING ROOFTOP RELIEF AIR GRAVITY HOOD. REMOVE ASSOCIATED CEILING GRILLE.
- EXISTING RELIEF AIR DISTRIBUTION TO REMAIN.
- EXISTING COMBUSTION AIR DUCT UP THRU' ROOF TO ROOFTOP GRAVITY HOOD TO REMAIN.

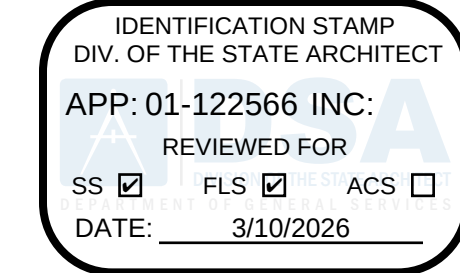

Revisions	Delta	Date	Revisions	By

KEY PLAN

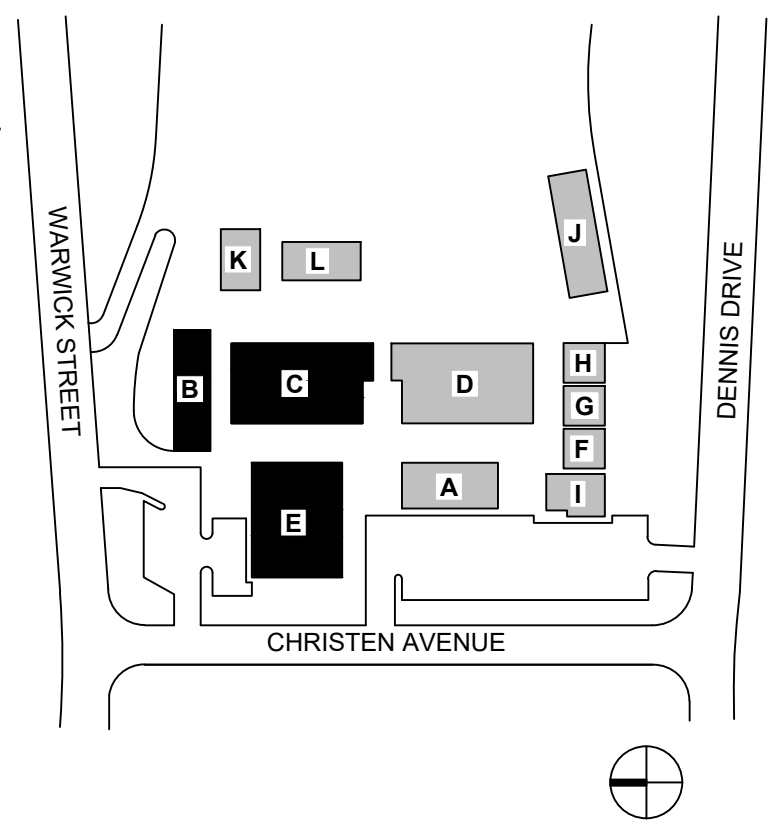

Consulting Engineers
5277 College Avenue
Oakland, CA 94618
Telephone (510) 837-9182

This document is the property of the Owner and is not to be used without their written permission



HY Architects Project number: Skyline Elementary School Project Number

Facility
SKYLINE ELEMENTARY SCHOOL
55 CHRISTEN AVE, DALY CITY, CA 94015


Project
HVAC REPLACEMENT

Sheet Title
BUILDINGS B, C, & E
MECHANICAL DEMOLITION
FLOOR PLANS

Client Project Number: 0000.0

Scale: As Indicated
Drawn By: CC
Checked By: AK
Issue Date:
Revit Version: 2023

Sheet
MD2.01
of

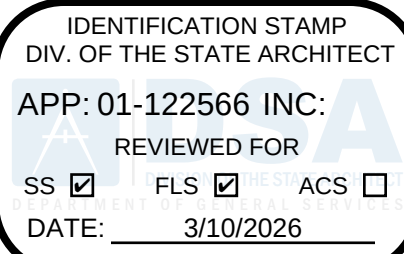

<div> <div> <div>#</div> <div>Revisions</div> </div> </div>			
Delta	Date	Revisions	By



Consulting Engineers
5277 College Avenue
Oakland, CA 94618
Telephone (510) 837-9182



HY HIBSER YAMAUCHI
Architects, Inc.
300 - 27th Street
Oakland, CA 94612
510.446.2222 tel | 510.446.2211 fax

HY Architects Project number:	Project Number
-------------------------------	----------------

Facility

SKYLINE ELEMENTARY SCHOOL
55 CHRISTEN AVE, DALY CITY, CA 94015

Project

HVAC REPLACEMENT

Sheet Title

BUILDINGS A & D MECHANICAL DEMOLITION FLOOR PLANS

Client Project Number:	0000.0
------------------------	--------

Scale: As Indicated

Drawn By: CC


Checked By: AK

Issue Date:

Sheet

MD2.02

Sheet of

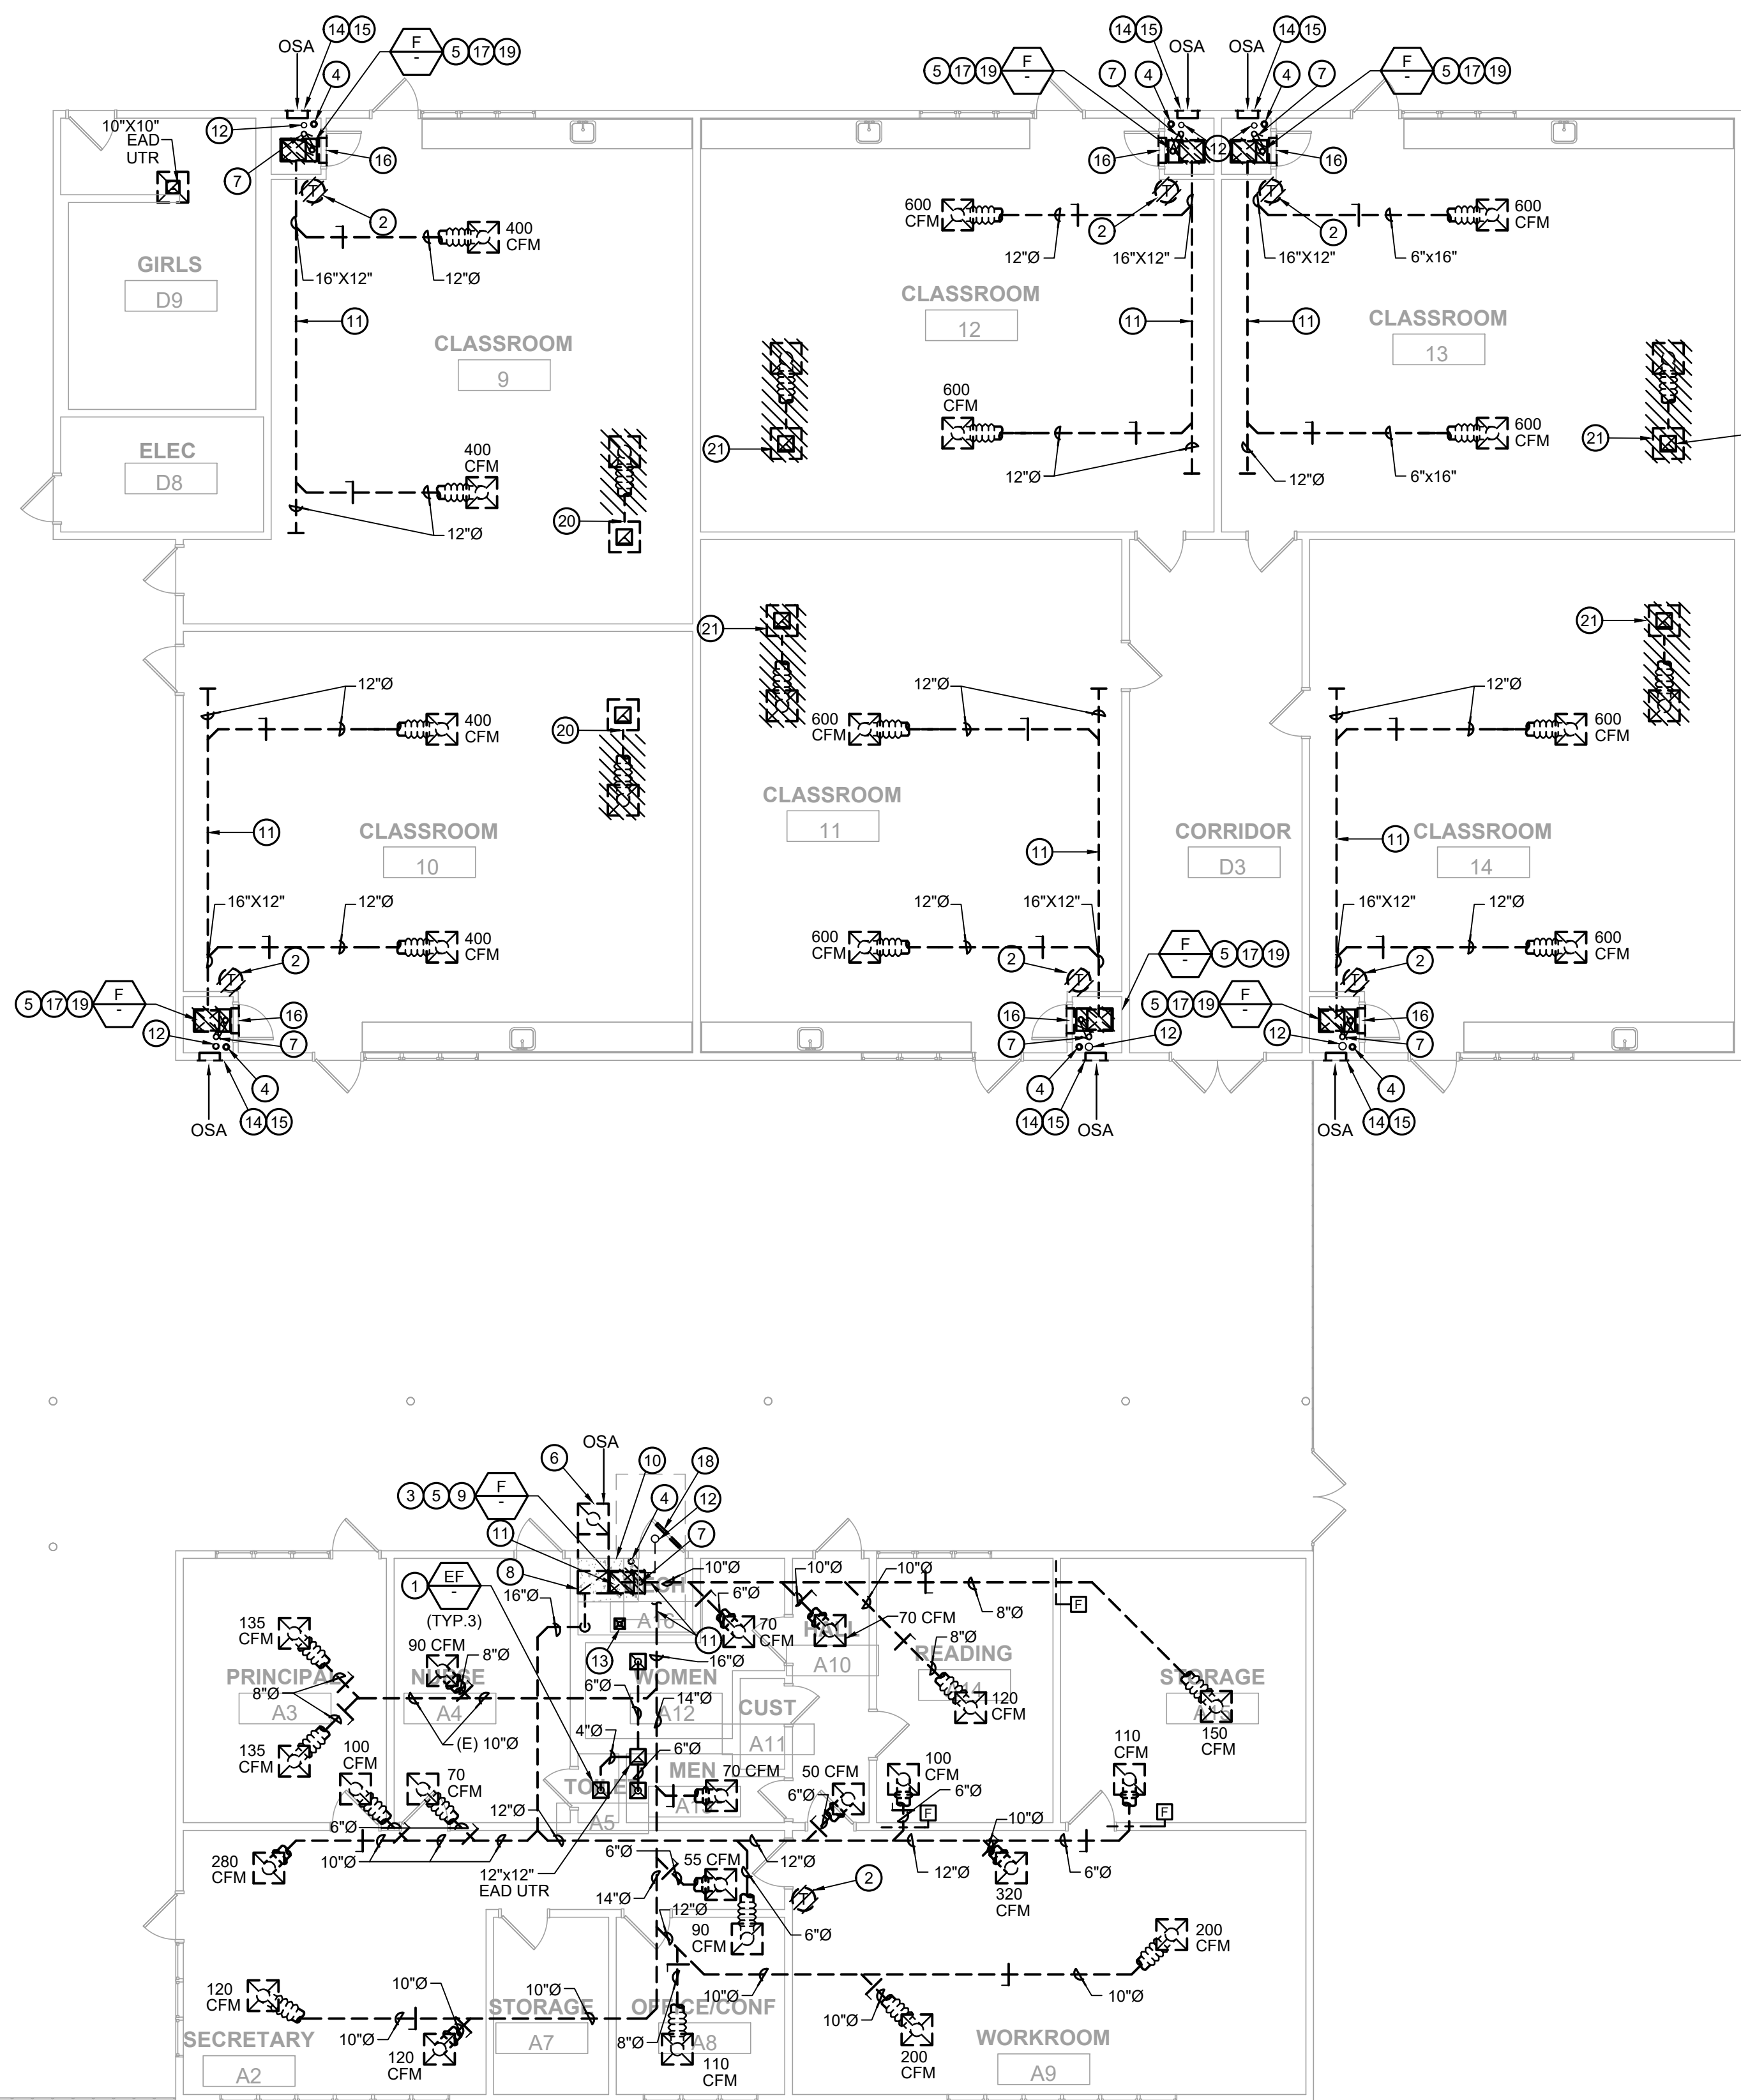

DEMOLITION CONSTRUCTION NOTES:

1. CONTRACTOR SHALL REUSE EXISTING OPENING(S) IN WALLS AND ANCHOR ROOF FOR FUTURE PIPING AND ETC WHEREVER POSSIBLE. COORDINATE WITH ARCHITECTURAL TRIM AS NECESSARY.
2. CONTRACTOR SHALL PATCH AND REPAIR EXISTING WALLS, FLOORS, CEILINGS, AND ROOF OPENINGS(S) AS NECESSARY FOR EXISTING HVAC EQUIPMENT, DUCTS, PIPING, ETC. BEING REMOVED AND/OR MODIFIED. MATCH SURROUNDING MATERIAL AND FINISH RATING.
3. EXISTING EXTERIOR WALL LOUVERS ARE BEING REPLACED WITH NEW BY ARCHITECTURAL. SEE ARCHITECTURAL DRAWINGS FOR ADDITIONAL INFORMATION.
4. REMOVE EXISTING DDC CONTROLLERS FROM ASSOCIATED EXISTING FURNACES AND SPLIT SYSTEMS BEING REMOVED. REMOVE EXISTING SHAFTS AND DUCTS FROM LOCATIONS. INSTALL UNITARY CONTROLLERS FOR NEW SYSTEM.
5. PROVIDE SS CONSTRUCTED COUNTERBALANCE BACKDRIFT DAMPERS FOR ALL BLDGS. RELIEF AIR FLOWS: HURDISHED AND INSTALLED BY MECHANICAL CONTRACTOR.
6. REPLACE EXISTING DDC CONTROLLERS WITH NEW INCLUDING ACTUATORS AND OSARA DAMPERS FOR ALL BUILDINGS. INSTALL EXISTING DUCTED DAMPERS INCLUDING LINKAGES BY MECHANICAL. 24V MOTORIZED DAMPER ACTUATORS BY CONTROL CONTRACTOR.
7. NO WALL OPENINGS ARE PERMITTED WITHOUT SEAL APPROVAL. EXCEPT RE-USING EXISTING OPENINGS AND MODIFICATION TO EXISTING DAMPERS. SEE ADDITIONAL NOTES ON THESE PLANS AND DETAILS ON STRUCTURAL DRAWINGS SB.01.

DEMOLITION KEY NOTES:

- 1 EXISTING EXHAUST FAN TO REMAIN.
- 2 REMOVE EXISTING FURNACE THERMOSTAT.
- 3 REMOVE EXISTING COOLING COIL CONDENSATE PIPING IN ITS ENTIRETY.
- 4 DISCONNECT EXISTING NG PIPING FROM FURNACE. RETAIN EXISTING NG SUPPLY PIPING FOR NEW WORK RE-CONNECTION.
- 5 REMOVE EXISTING GAS FIRED FURNACE AND ASSOCIATED APPLIANCES INCLUDING BUT NOT LIMITED TO CONTROL SUPPORTS, AND COOLING COIL. SEE ELECTRICAL DRAWINGS FOR ADDITIONAL INFORMATION.
- 6 REMOVE EXISTING OSA DUCT WITHIN WALKWAY CEILING SPACE UP THRU ROOF TO ROOFTOP GRAVITY HOOD. DEMOLISH EXISTING OSA DUCT FROM FURNACE.
- 7 REMOVE EXISTING FLUE PIPING AND RISER UP THRU ROOF FROM EXISTING FURNACE.
- 8 REMOVE EXISTING RETURN AIR PLENUM UP TO OSA DUCT.
- 9 DEMOLISH EXISTING AIR MIXING BOX.
- 10 EXISTING CONCRETE PAD TO REMAIN.
- 11 EXISTING SUPPLY/RETURN AIR DISTRIBUTION TO REMAIN. DISCONNECT DUCTS FROM EXISTING FURNACE TO BE REMOVED AND RECONNECT AT NEW WORK INSTALLATION.
- 12 DEMOLISH EXISTING SPLIT SYSTEM REFRIGERANT PIPING (RG & RU) IN ITS ENTIRETY.
- 13 EXISTING FLOOR SINK TO REMAIN.
- 14 EXISTING LOW WALL MOUNTED OSA EXTERIOR LOUVER AT AIR MIXING BOX SHALL BE REPLACED WITH NEW BY ARCHITECTURAL.
- 15 EXISTING HIGH WALL MOUNTED COMBUSTION AIR EXTERIOR LOUVER SHALL BE REPLACED WITH NEW BY ARCHITECTURAL. DEMOLISH EXISTING ASSOCIATED DUCTWORK.
- 16 RETAIN EXISTING RETURN AIR GRILLE AT AIR MIXING BOX.
- 17 EXISTING FURNACE CLOCKSET AND AIR MIXING BOX SHALL REMAIN FULLY INTACT BY CONTRACTOR. REPLACE EXISTING LINING WITH NEW AND REMOVE FERR RACK AT TOP OF AIR MIXING BOX. SEE ARCHITECTURAL DRAWINGS FOR ADDITIONAL INFORMATION.
- 18 EXISTING HIGH AND LOW DOOR LOUVERS SHALL BE REPLACED WITH NEW BY ARCHITECTURE. SEE ARCHITECTURAL DRAWINGS FOR ADDITIONAL INFORMATION.
- 19 REMOVE EXISTING COOLING COIL CONDENSATE PIPING IN ITS ENTIRETY INCLUDING CONDENSATE PUMP. RETAIN EXISTING POWER FOR NEW WORK.
- 20 DEMOLISH EXISTING RELIEF AIR DUCT UP THRU ROOF TO EXISTING ROOFTOP RELIEF AIR GRAVITY HOOD. REMOVE ASSOCIATED CEILING GRILLE.
- 21 REMOVE EXISTING RELIEF AIR DUCT UP THRU ROOF FROM ROOFTOP RELIEF AIR GRAVITY HOOD TO REMAIN.

This document is the property of the Owner and is not to be used without their written permission



HY HIBSER YAMAUCHI
Architects, Inc.

300 - 27th Street
Oakland, CA 94612
510.446.2222 tel | 510.446.2211 fax

HY Architects Project number:	Project Number
-------------------------------	----------------

Facility

SKYLINE ELEMENTARY SCHOOL
55 CHRISTEN AVE, DALY CITY, CA 94015

Project

HVAC REPLACEMENT

Sheet Title

BUILDINGS A & D MECHANICAL DEMOLITION FLOOR PLANS

Client Project Number:	0000.0
------------------------	--------

Scale: As Indicated

Drawn By: CC

Checked By: AK

Issue Date:


Sheet

MD2.02

Sheet of

[illegible]

KEY PLAN

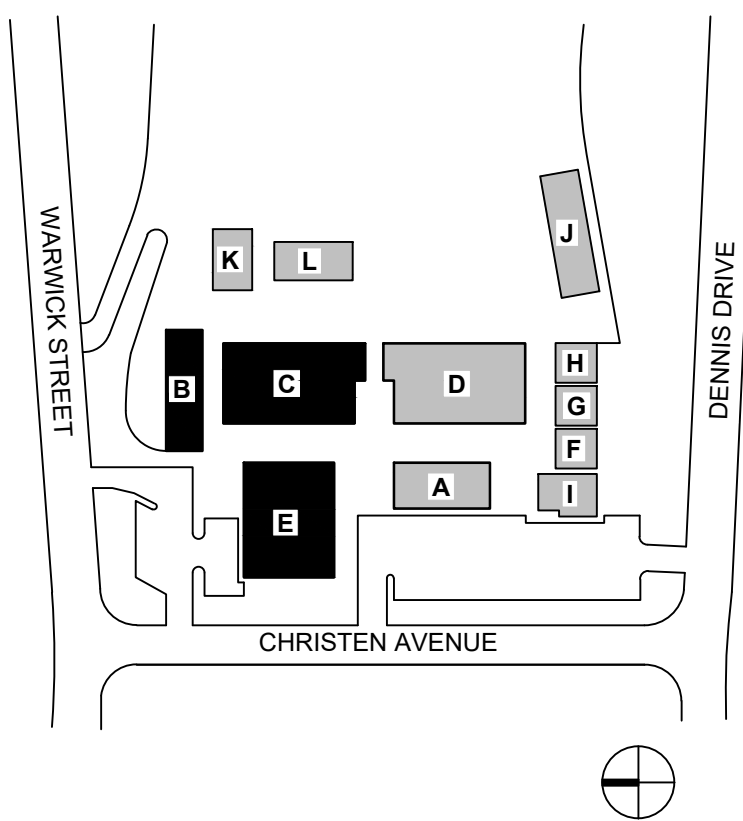

Consulting Engineers
5277 College Avenue
Oakland, CA 94618
Telephone (510) 837-9182



HY Architects Project number:	Project Number
-------------------------------	----------------

Facility	SKYLINE ELEMENTARY SCHOOL 55 CHRISTEN AVE, DALY CITY, CA 94015
----------	---


Project








HVAC REPLACEMENT

Sheet Title


BUILDINGS B, C & E
MECHANICAL DEMOLITION
ROOF PLAN

Client Project Number:		0000.0
Scale:	As Indicated	Sheet
Drawn By:	CC	MD2.03
Checked By:	AK	
Issue Date:		
Revit Version:	2023	Sheet of

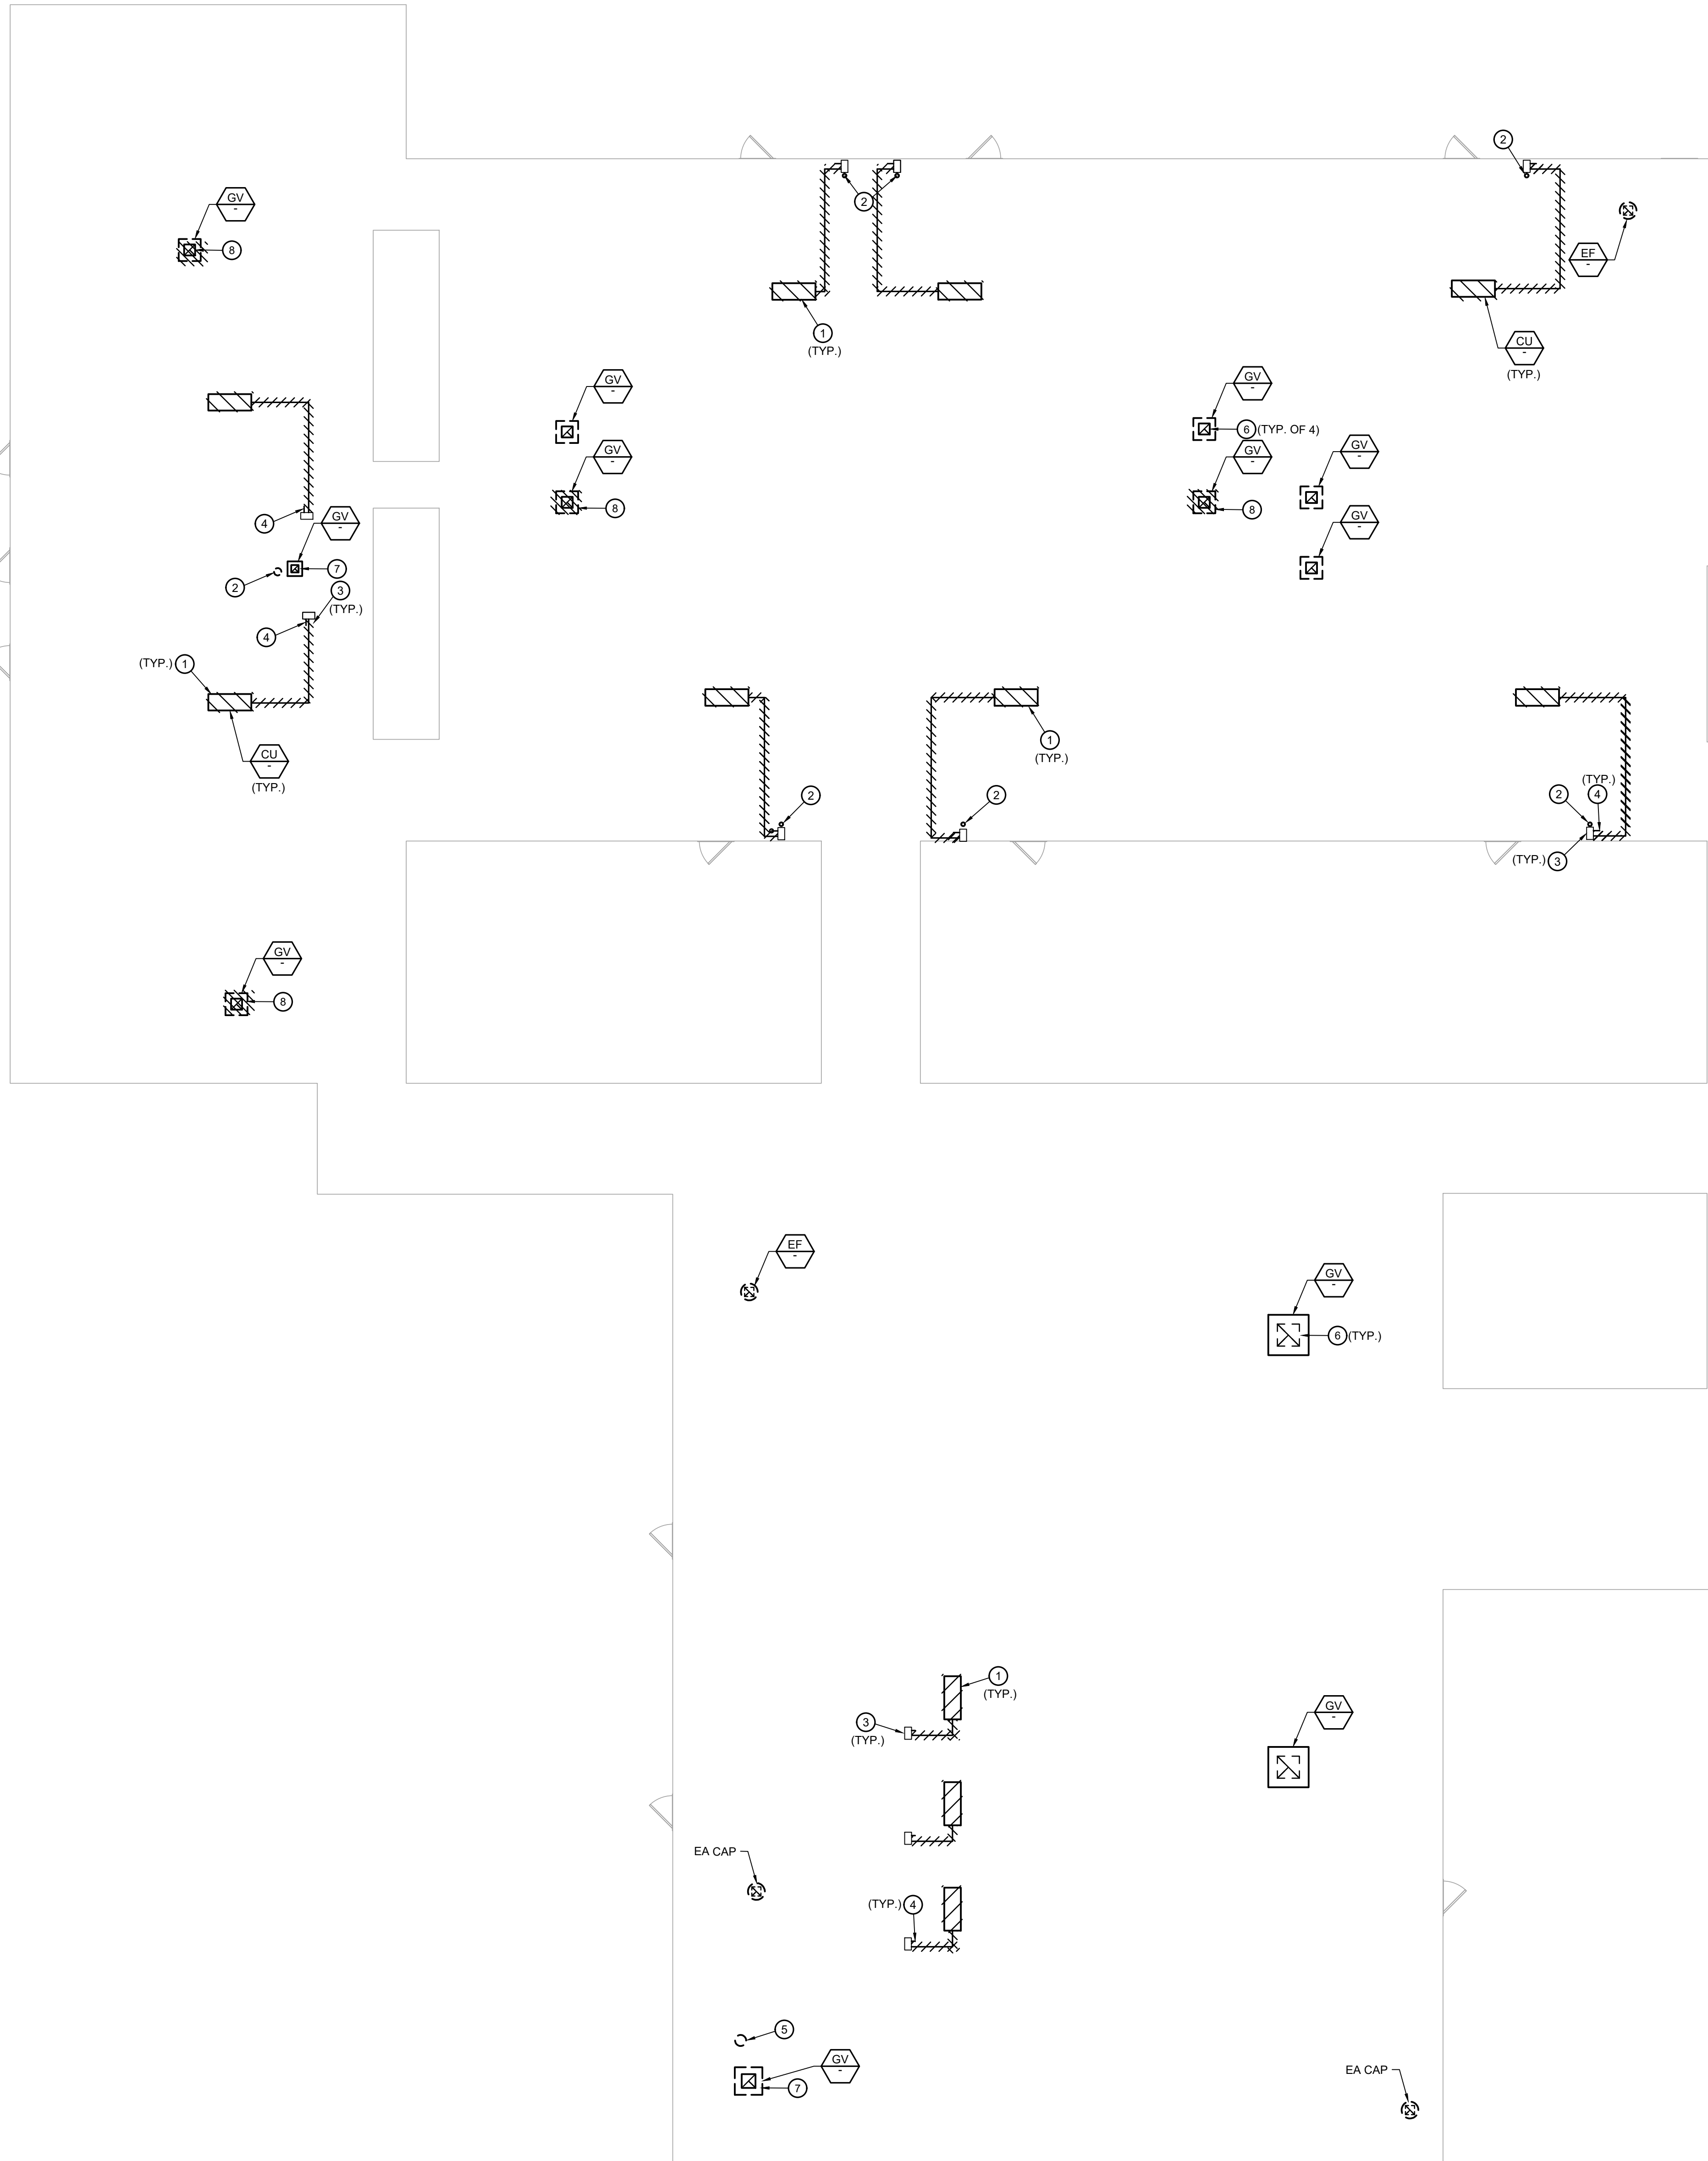


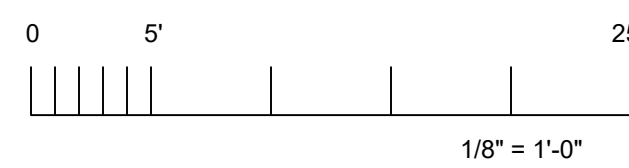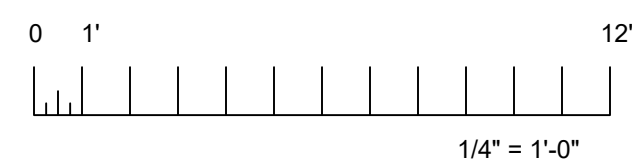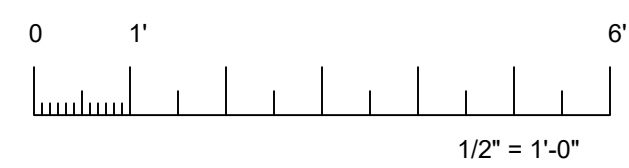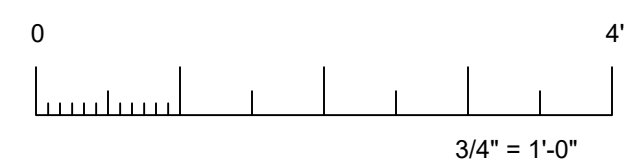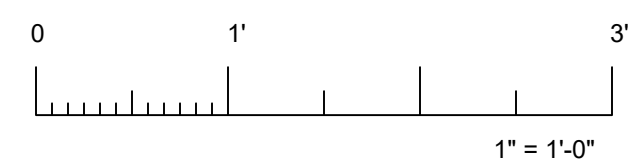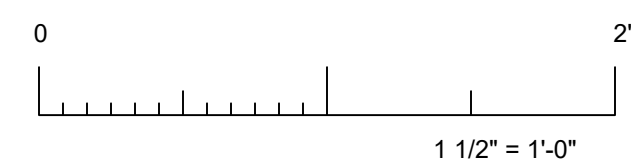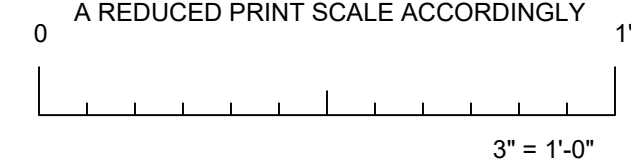

IF THIS SHEET IS NOT 30"x42" , IT IS

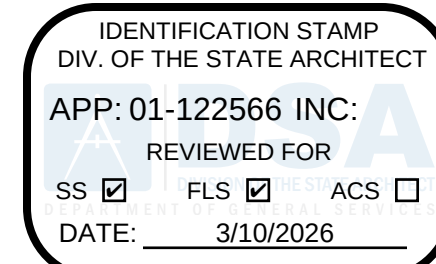[illegible]

KEY PLAN

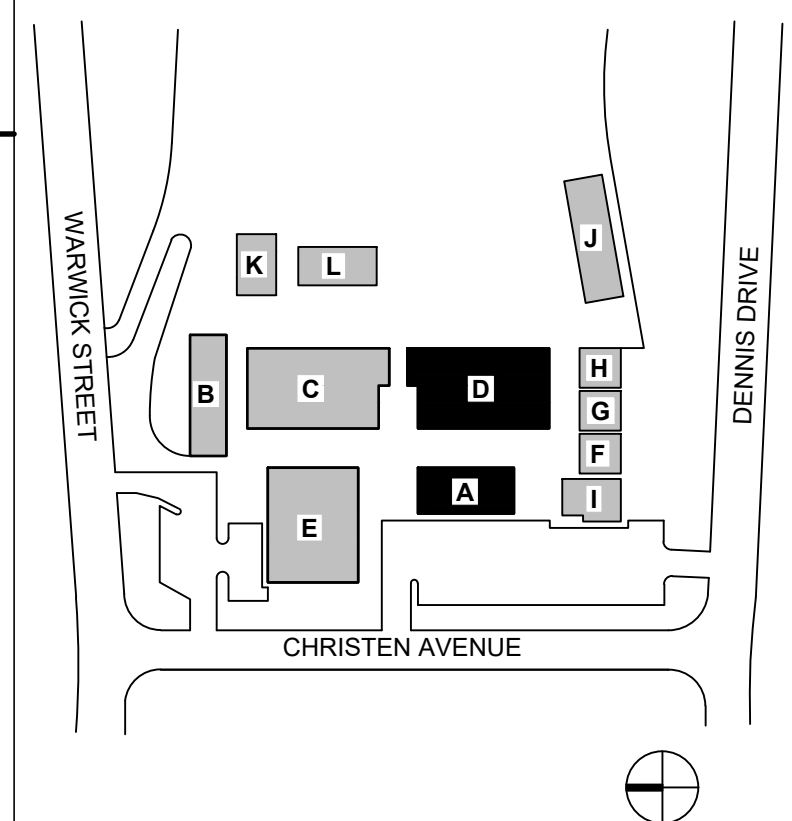

Consulting Engineers
5277 College Avenue
Oakland, CA 94618
Telephone (510) 837-9182

This document is the property of the Owner and is not to be used without their written permission.



HY Architects Project number:	Project Number
-------------------------------	----------------

Facility	SKYLINE ELEMENTARY SCHOOL 55 CHRISTEN AVE, DALY CITY, CA 94015
----------	---

Project

HVAC REPLACEMENT

Sheet Title

BUILDINGS A & D MECHANICAL
DEMOLITION ROOF PLAN

Client Project Number:	0000.0
------------------------	--------

Scale: As Indicated

Drawn By: CC

Checked By: AK

Issue Date

Revit Version: 202

She

MD2.04

Sheet of






BUILDINGS A & D MECHANICAL DEMOLITION ROOF PLAN

$$1/8" = 1'-0"$$

1


3/26/2025 3:12:50 PM M:\P - PROJECTS\2025\502-25-0001 SFUSD SKYLINE ES\02_MECH

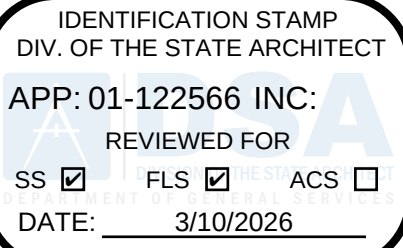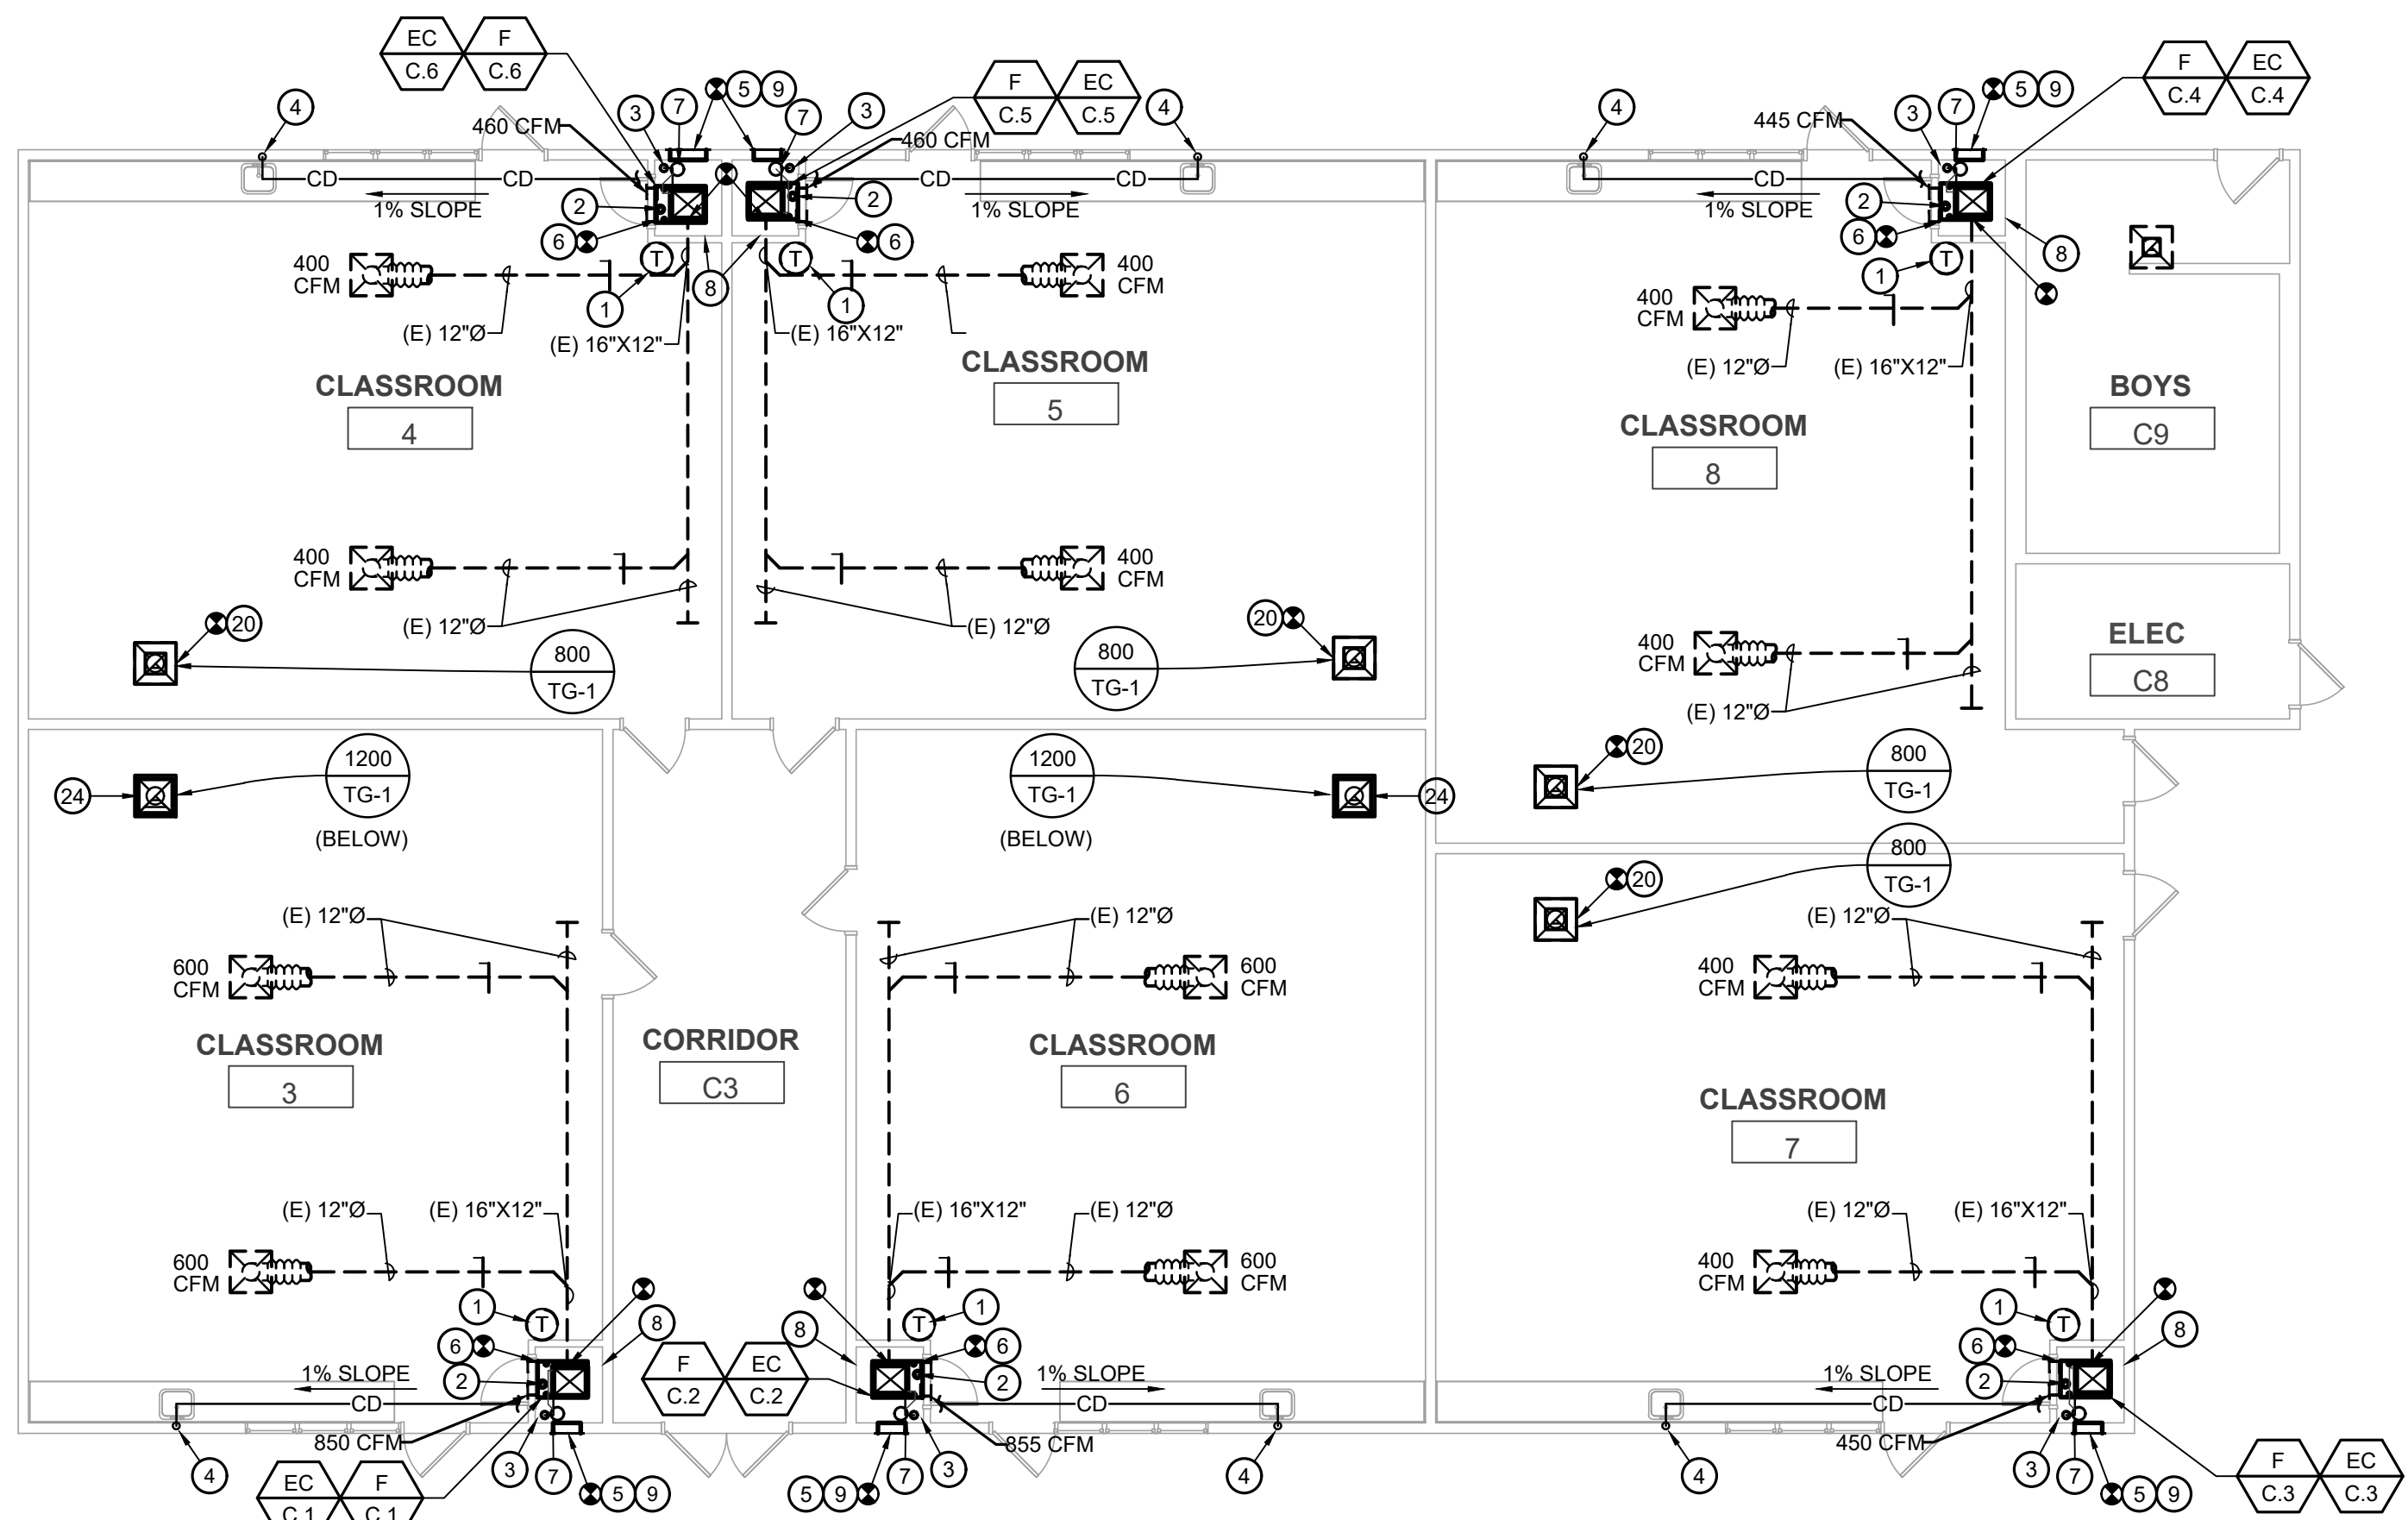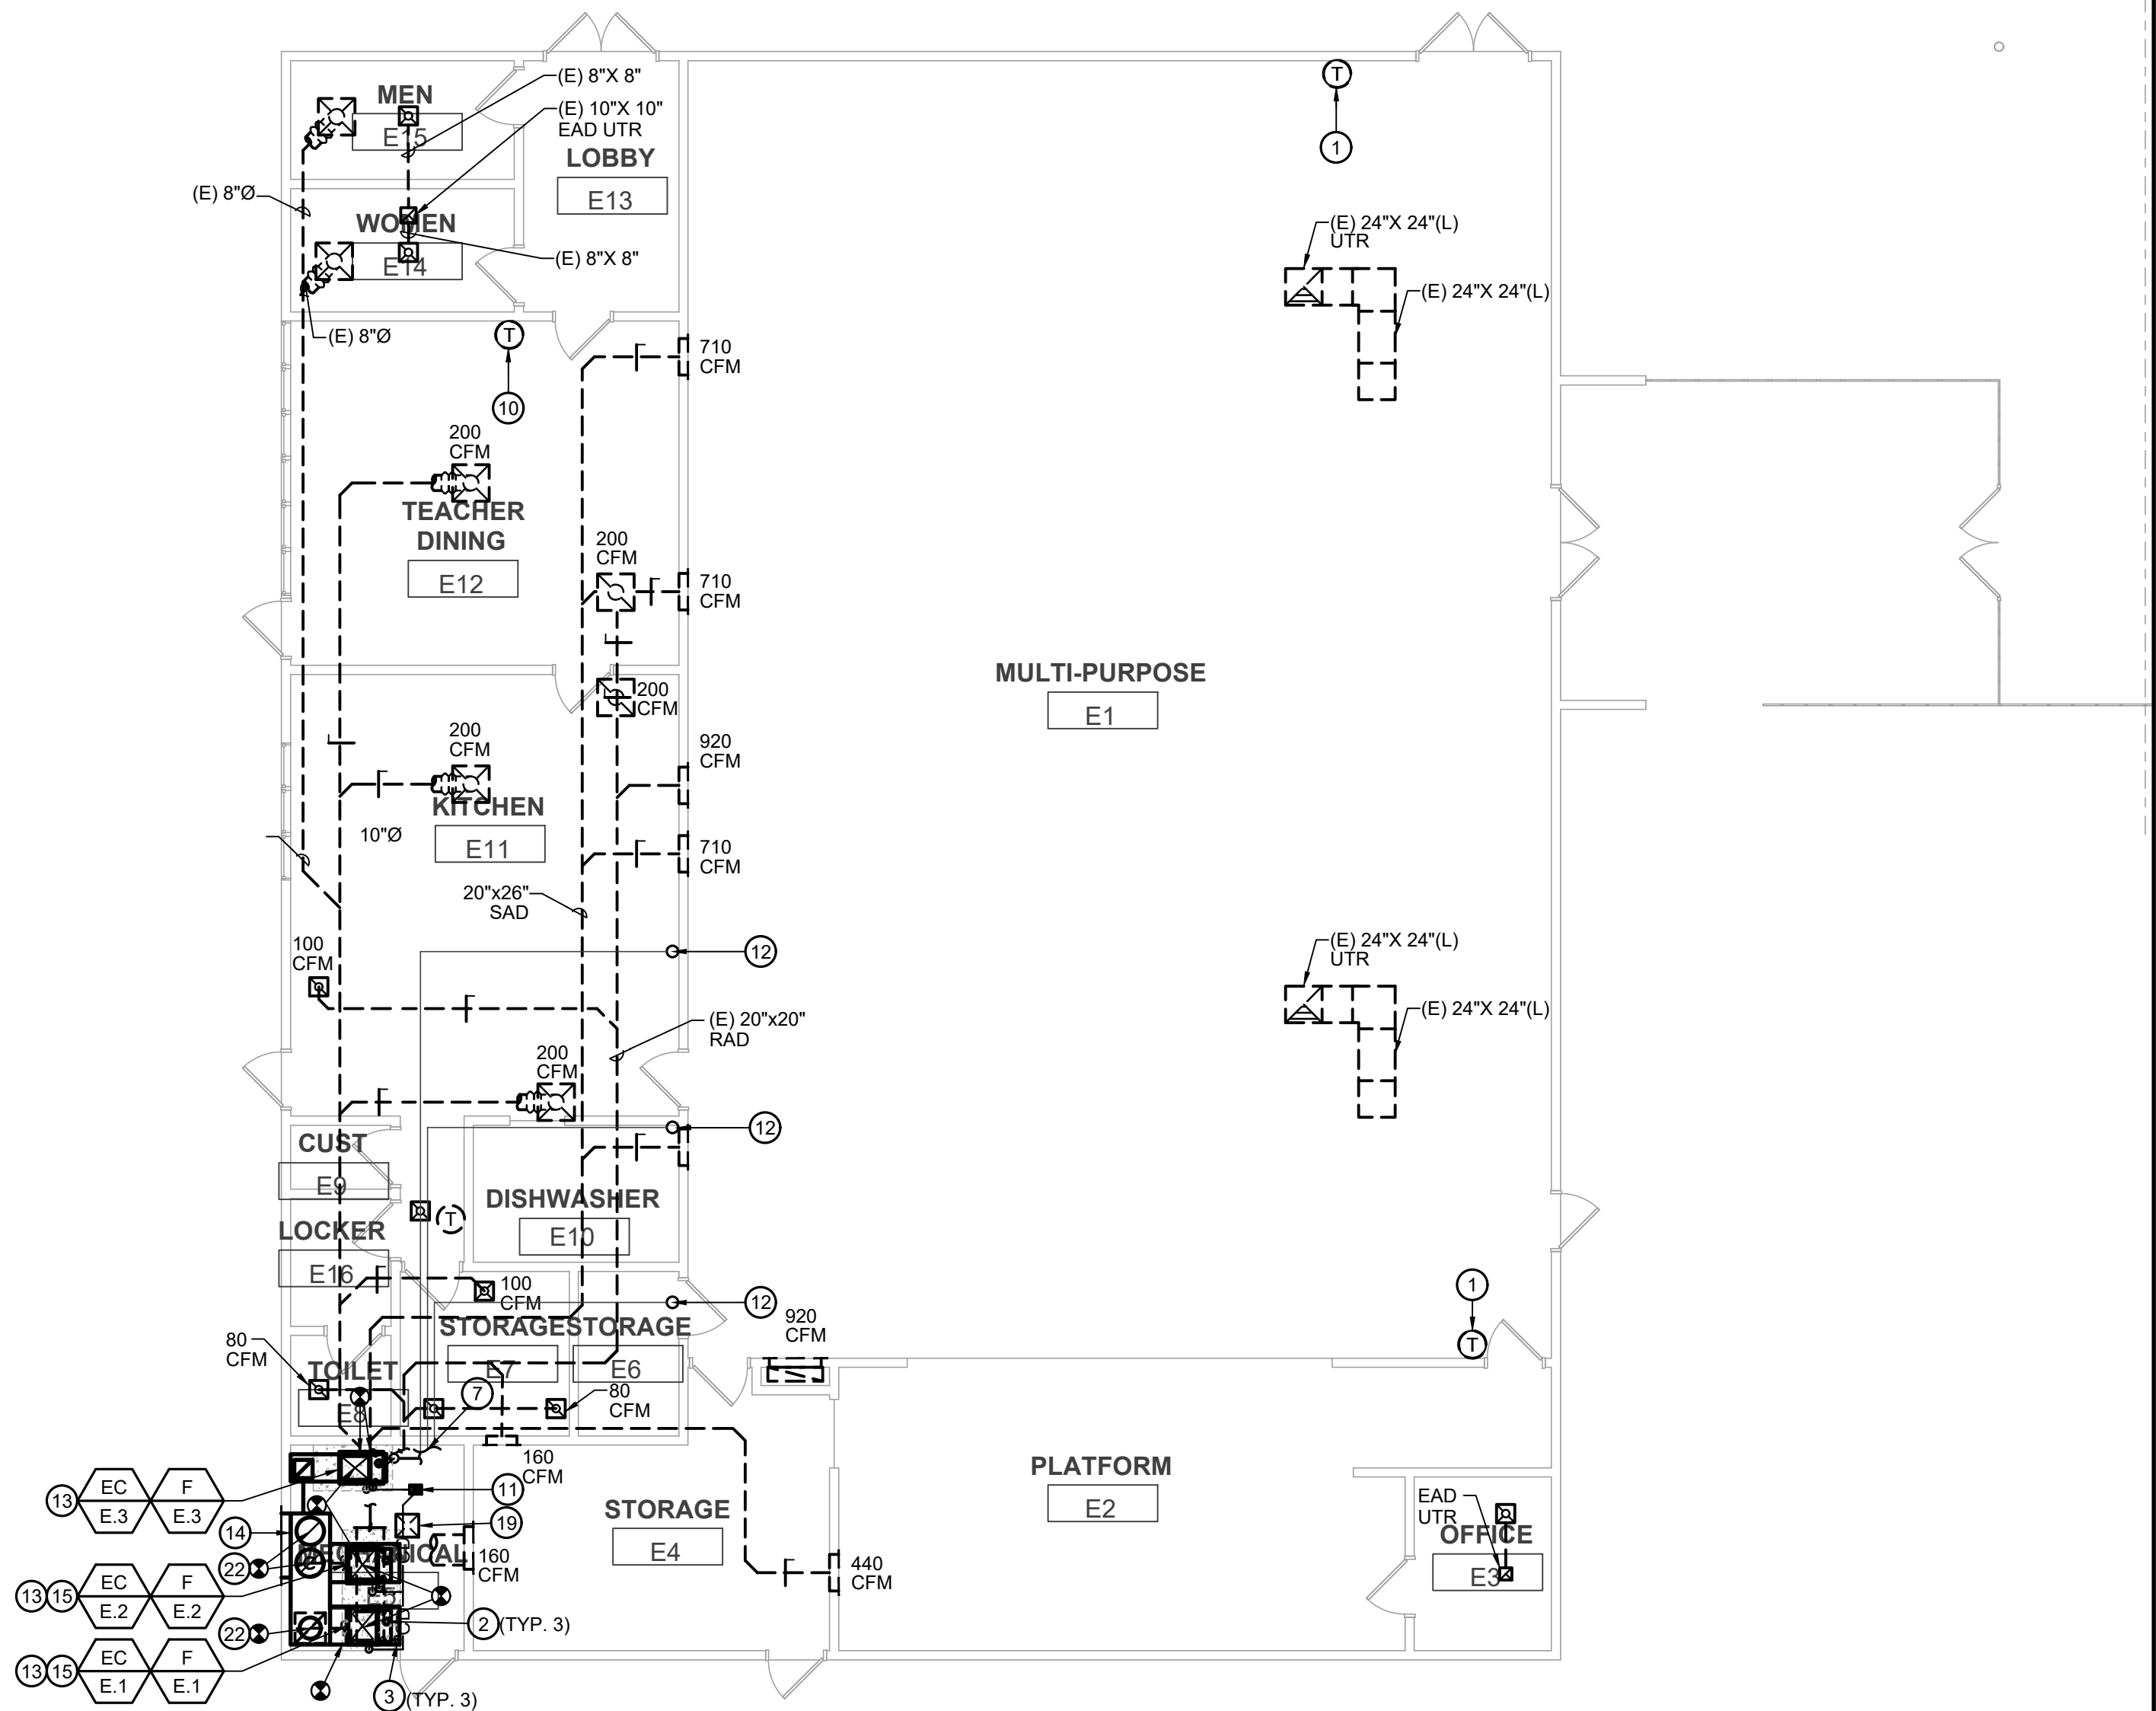

- 1 NEW ELECTRONIC THERMOSTAT WITH CO2 SENSOR FOR FURNACE. MOUNT AT 48" A.F.F.
- 2 CONNECT NEW 2.5" VENT AND COMBUSTION AIR INTAKE TO UNIT WITH 3" CONCENTRIC VENT UP THRU ROOF. RE-USE EXISTING ROOF OPENING AND MODIFY AS NECESSARY.
- 3 CONNECT NEW NG PIPING FROM FURNACE TO EXISTING NG SUPPLY PIPING.
- 4 NEW 3/4" CD PIPING DOWN INSIDE WALL TO SINK TAILPIECE FROM CONDENSING FURNACE AND COOLING COIL. PROVIDE P-TRAP AT UNIT.
- 5 ROUTE NEW OSA DUCT TO NEW LOW WALL MOUNTED OSA EXTERIOR WALL LOUVER W/ INSECT SCREEN AT AIR MIXING BOX. SEE ARCHITECTURAL DRAWING FOR ADDITIONAL INFORMATION.
- 6 EXISTING RETURN AIR GRILLE TO REMAIN.
- 7 CONNECT NEW REFRIGERANT PIPING (RG & RL) FROM ROOFTOP CONDENSING UNIT TO COOLING COIL.
- 8 EXISTING FURNACE CLOSET AND AIR MIXING BOX TO REMAIN. SEE ARCHITECTURAL DRAWINGS FOR ADDITIONAL INFORMATION.
- 9 ROUTE NEW OSA DUCT TO NEW HIGH WALL OSA EXTERIOR WALL LOUVER W/ INSECT SCREEN. SEE ARCHITECTURAL DRAWINGS FOR ADDITIONAL INFORMATION.
- 10 NEW ELECTRONIC THERMOSTAT FOR FURNACE. MOUNT AT 48" A.F.F.
- 11 NEW 3/4" CD PIPING DOWN TO FLOOR DRAIN WITH 1" AIR GAP.
- 12 NEW REFRIGERANT PIPING UP THRU ROOF TO ROOFTOP CONDENSING UNIT. RE-USE EXISTING ROOF OPENING AND MODIFY AS NECESSARY.
- 13 INSTALL NEW AIR MIXING BOX WITH LINING AND FILTER RACK MOUNTED ON TOP. PROVIDE A MIN. 26" DEEP PLENUM OVER NEW OSA EXTERIOR WALL LOUVER W/ INSECT SCREEN. SEE ARCHITECTURAL DRAWINGS FOR ADDITIONAL INFORMATION.
- 15 RE-INSTALL EXISTING DUCT MOUNTED SMOKE DETECTOR(S).
- 16 ROUTE NEW OSA DUCT W/VD TO NEW LOW WALL MOUNTED OSA EXTERIOR WALL LOUVER W/ INSECT SCREEN. SEE ARCHITECTURAL DRAWINGS FOR ADDITIONAL INFORMATION.
- 17 ROUTE NEW OSA DUCT W/VD TO NEW HIGH WALL MOUNTED OSA EXTERIOR WALL LOUVER W/ INSECT SCREEN AT AIR MIXING BOX. SEE ARCHITECTURAL DRAWING FOR ADDITIONAL INFORMATION.
- 18 INSTALL NEW AIR MIXING BOX WITH LINING AND FILTER RACK MOUNTED ON SIDE OF FURNACE. NEW AIR MIXING BOX FOOTPRINT SIZE SHALL MATCH EXISTING.
- 19 EXISTING COMBUSTION AIR DUCT UP THRU ROOF TO ROOFTOP GRAVITY HOOD TO REMAIN. ABANDON IN PLACE.
- 20 PROVIDE NEW 18"X18" UP THRU ROOF. RECONNECT NEW RELIEF AIR DUCT TO EXISTING DUCT DOWN THRU ROOF.
- 21 PROVIDE NEW 14"X30" RELIEF AIR DUCT UP THRU ROOF TO GRAVITY RELIEF HOOD.
- 22 RECONNECT EXISTING RETURN DUCT WORK TO NEW PLENUM.
- 23 CONNECT NEW 2.5" VENT AND COMBUSTION AIR INTAKE TO UNIT WITH 3" CONCENTRIC VENT UP THRU ROOF.
- 24 PROVIDE NEW 20"X20" RELIEF AIR DUCT UP THRU ROOF TO GRAVITY RELIEF HOOD.



KEY PLAN

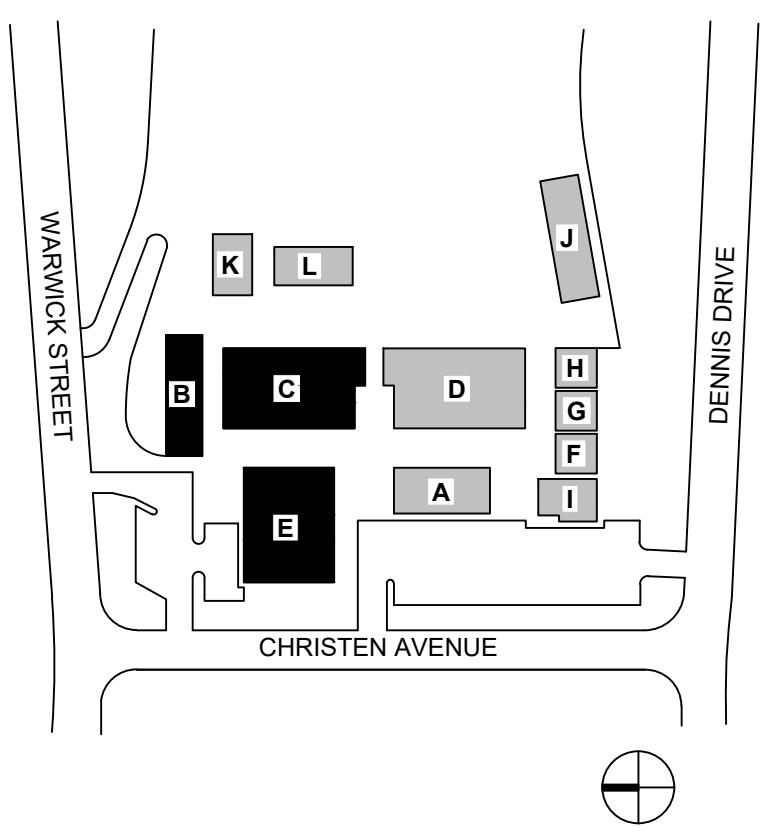

Consulting Engineers
5277 College Avenue
Oakland, CA 94618
Telephone (510) 837-9182



HY HIBSER YAMAUCHI
Architects, Inc.

300 - 27th Street
Oakland, CA 94612
510.446.2222 tel | 510.446.2211 fax

HY Architects Project number:	Project Number
-------------------------------	----------------

Facility

SKYLINE ELEMENTARY SCHOOL
55 CHRISTEN AVE, DALY CITY, CA 94015

Project

HVAC REPLACEMENT

Sheet Title

BUILDINGS B, C, & E
MECHANICAL NEW WORK
FLOOR PLANS

Client Project Number: 0000.0

Scale: As Indicated



Drawn By: CC

Checked By: AK

Issue Date:

M2.01

Sheet of

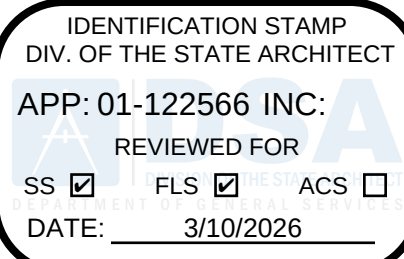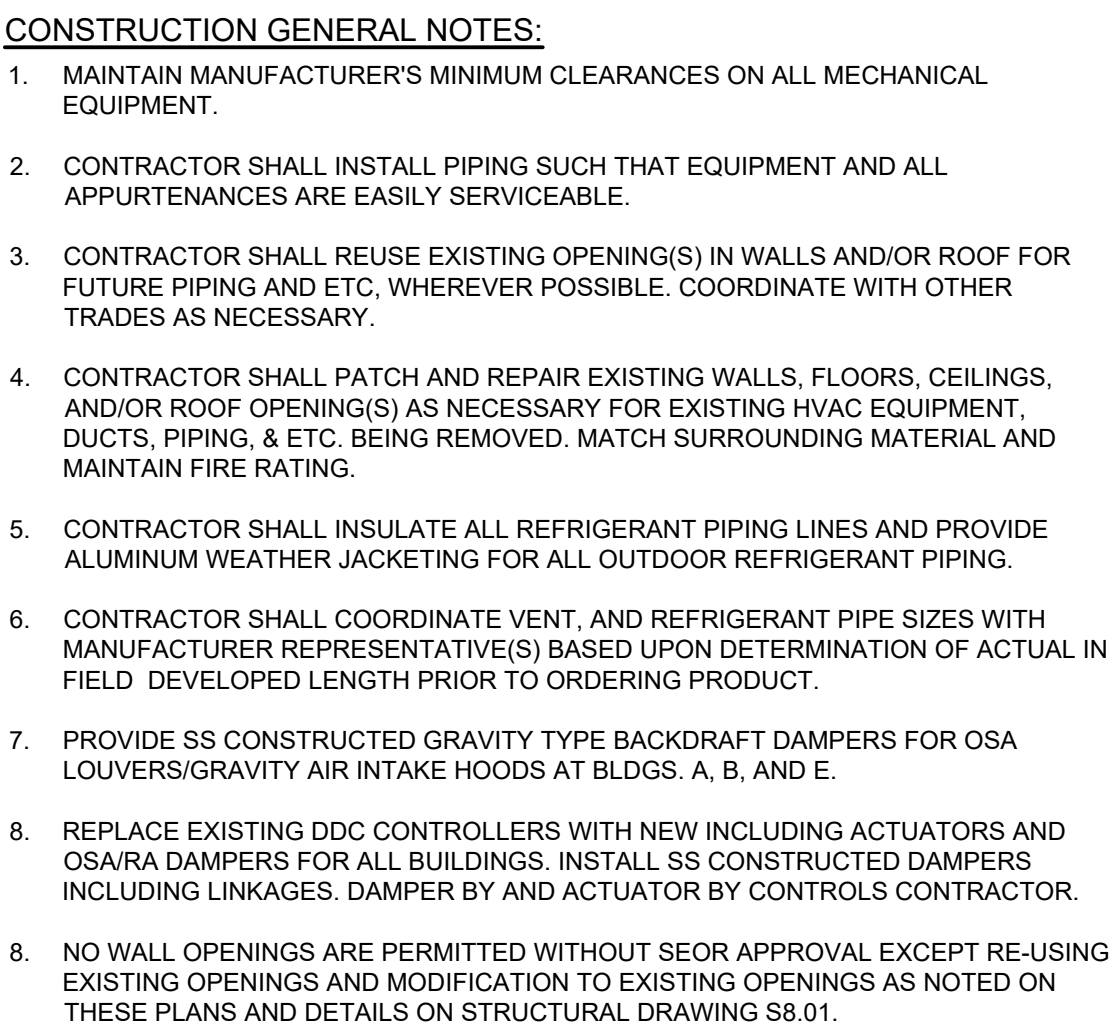

- ① NEW ELECTRONIC THERMOSTAT WITH CO2 SENSOR FOR FURNACE. MOUNT AT 48" A.F.F.
- ② CONNECT NEW 2.5" VENT AND COMBUSTION AIR INTAKE TO UNIT 3" CONCENTRIC VENT UP THRU' ROOF. RE-USE EXISTING ROOF OPENING AND MODIFY AS NECESSARY.
- ③ CONNECT NEW NG PIPING FROM FURNACE TO EXISTING NG SUPPLY PIPING.
- ④ NEW 3/4" CP PIPING DOWN INSIDE WALL TO SINK TAILPIECE FROM CONDENSING FURNACE AND COOLING COIL. PROVIDE P-TRAP AT UNIT.
- ⑤ ROUTE NEW OSA DUCT TO NEW LOW WALL MOUNTED OSA EXTERIOR WALL. LOWER W/ INSET SCREEN AT AIR MIXING BOX. SEE ARCHITECTURAL DRAWING FOR ADDITIONAL INFORMATION.
- ⑥ EXISTING RETURN AIR GRILLE TO REMAIN.
- ⑦ CONNECT NEW REFRIGERANT PIPING (RG & RL) FROM ROOFTOP CONDENSING UNIT TO COOLING COIL.
- ⑧ EXISTING FURNACE CLOSET AND AIR MIXING BOX TO REMAIN. SEE ARCHITECTURAL DRAWINGS FOR ADDITIONAL INFORMATION.
- ⑨ ROUTE NEW OSA DUCT TO NEW HIGH WALL MOUNTED OSA AIR EXTERIOR WALL. LOWER. SEE ARCHITECTURAL DRAWINGS FOR ADDITIONAL INFORMATION.
- ⑩ NEW ELECTRONIC THERMOSTAT FOR FURNACE. MOUNT AT 48" A.F.F.
- ⑪ NEW 3/4" CP PIPING DOWN TO FLOOR DRAIN WITH 1" AIR GAP.
- ⑫ NEW 24"x24" OSA DUCT WITHIN WALKWAY CEILING SPACE UP THRU' ROOF TO ROOFTOP GRAVITY HOOD.
- ⑬ INSTALL NEW AIR MIXING BOX WITH LINING AND FILTER RACK MOUNTED ON TOP OF NEW AIR MIXING BOX FOOTPRINT SIZE SHALL MATCH EXISTING.
- ⑭ NEW DOOR LOUVERS BY ARCHITECTURAL. SEE ARCHITECTURAL DRAWINGS FOR ADDITIONAL INFORMATION.
- ⑮ PROVIDE NEW 18" x 18" RELIEF AIR DUCT UP THRU' ROOF TO GRAVITY RELIEF HOOD.
- ⑯ PROVIDE NEW 18"x18" UP THRU' ROOF. RECONNECT NEW RELIEF AIR DUCT TO EXISTING DUCT DOWN THRU' ROOF.
- ⑰ CONNECT NEW 24"x24" OSA DUCT TO EXISTING OSA/RETURN AIR PLENUM. CONTRACTOR TO PROVIDE TRANSITIONS AS NECESSARY TO MAKE CONNECTIONS.
- ⑱ PROVIDE NEW 20"x20" RELIEF AIR DUCT UP THRU' ROOF TO GRAVITY RELIEF HOOD.

WARWICK STREET

DENNIS DRIVE

CHRISTEN AVENUE

Buildings labeled: A, B, C, D, E, F, G, H, I, J, K, L

Consulting Engineers
5277 College Avenue
Oakland, CA 94618
Telephone (510) 837-9182

This document is the property of the Owner and is not to be used without their written permission



HY HIBSER YAMAUCHI
Architects, Inc.
300 – 27th Street
Oakland, CA 94612
510.446.2222 tel | 510.446.2211 fax

HY Architects Project number:	Project Number
-------------------------------	----------------

Facility	SKYLINE ELEMENTARY SCHOOL 55 CHRISTEN AVE, DALY CITY, CA 94015
----------	---

Project

HVAC REPLACEMENT

Sheet Title

BUILDINGS A & D MECHANICAL NEW WORK FLOOR PLANS

Client Project Number: 0000.0

Scale: As Indicated

Drawn By: CC

Checked By: AK


Issue Date:

M2.02

Sheet of

of

3/20/2023 3:12:50 PM M:\P - PROJECTS\2025\002-25-0001 SFUSD SKYLINE ES\02_MECH

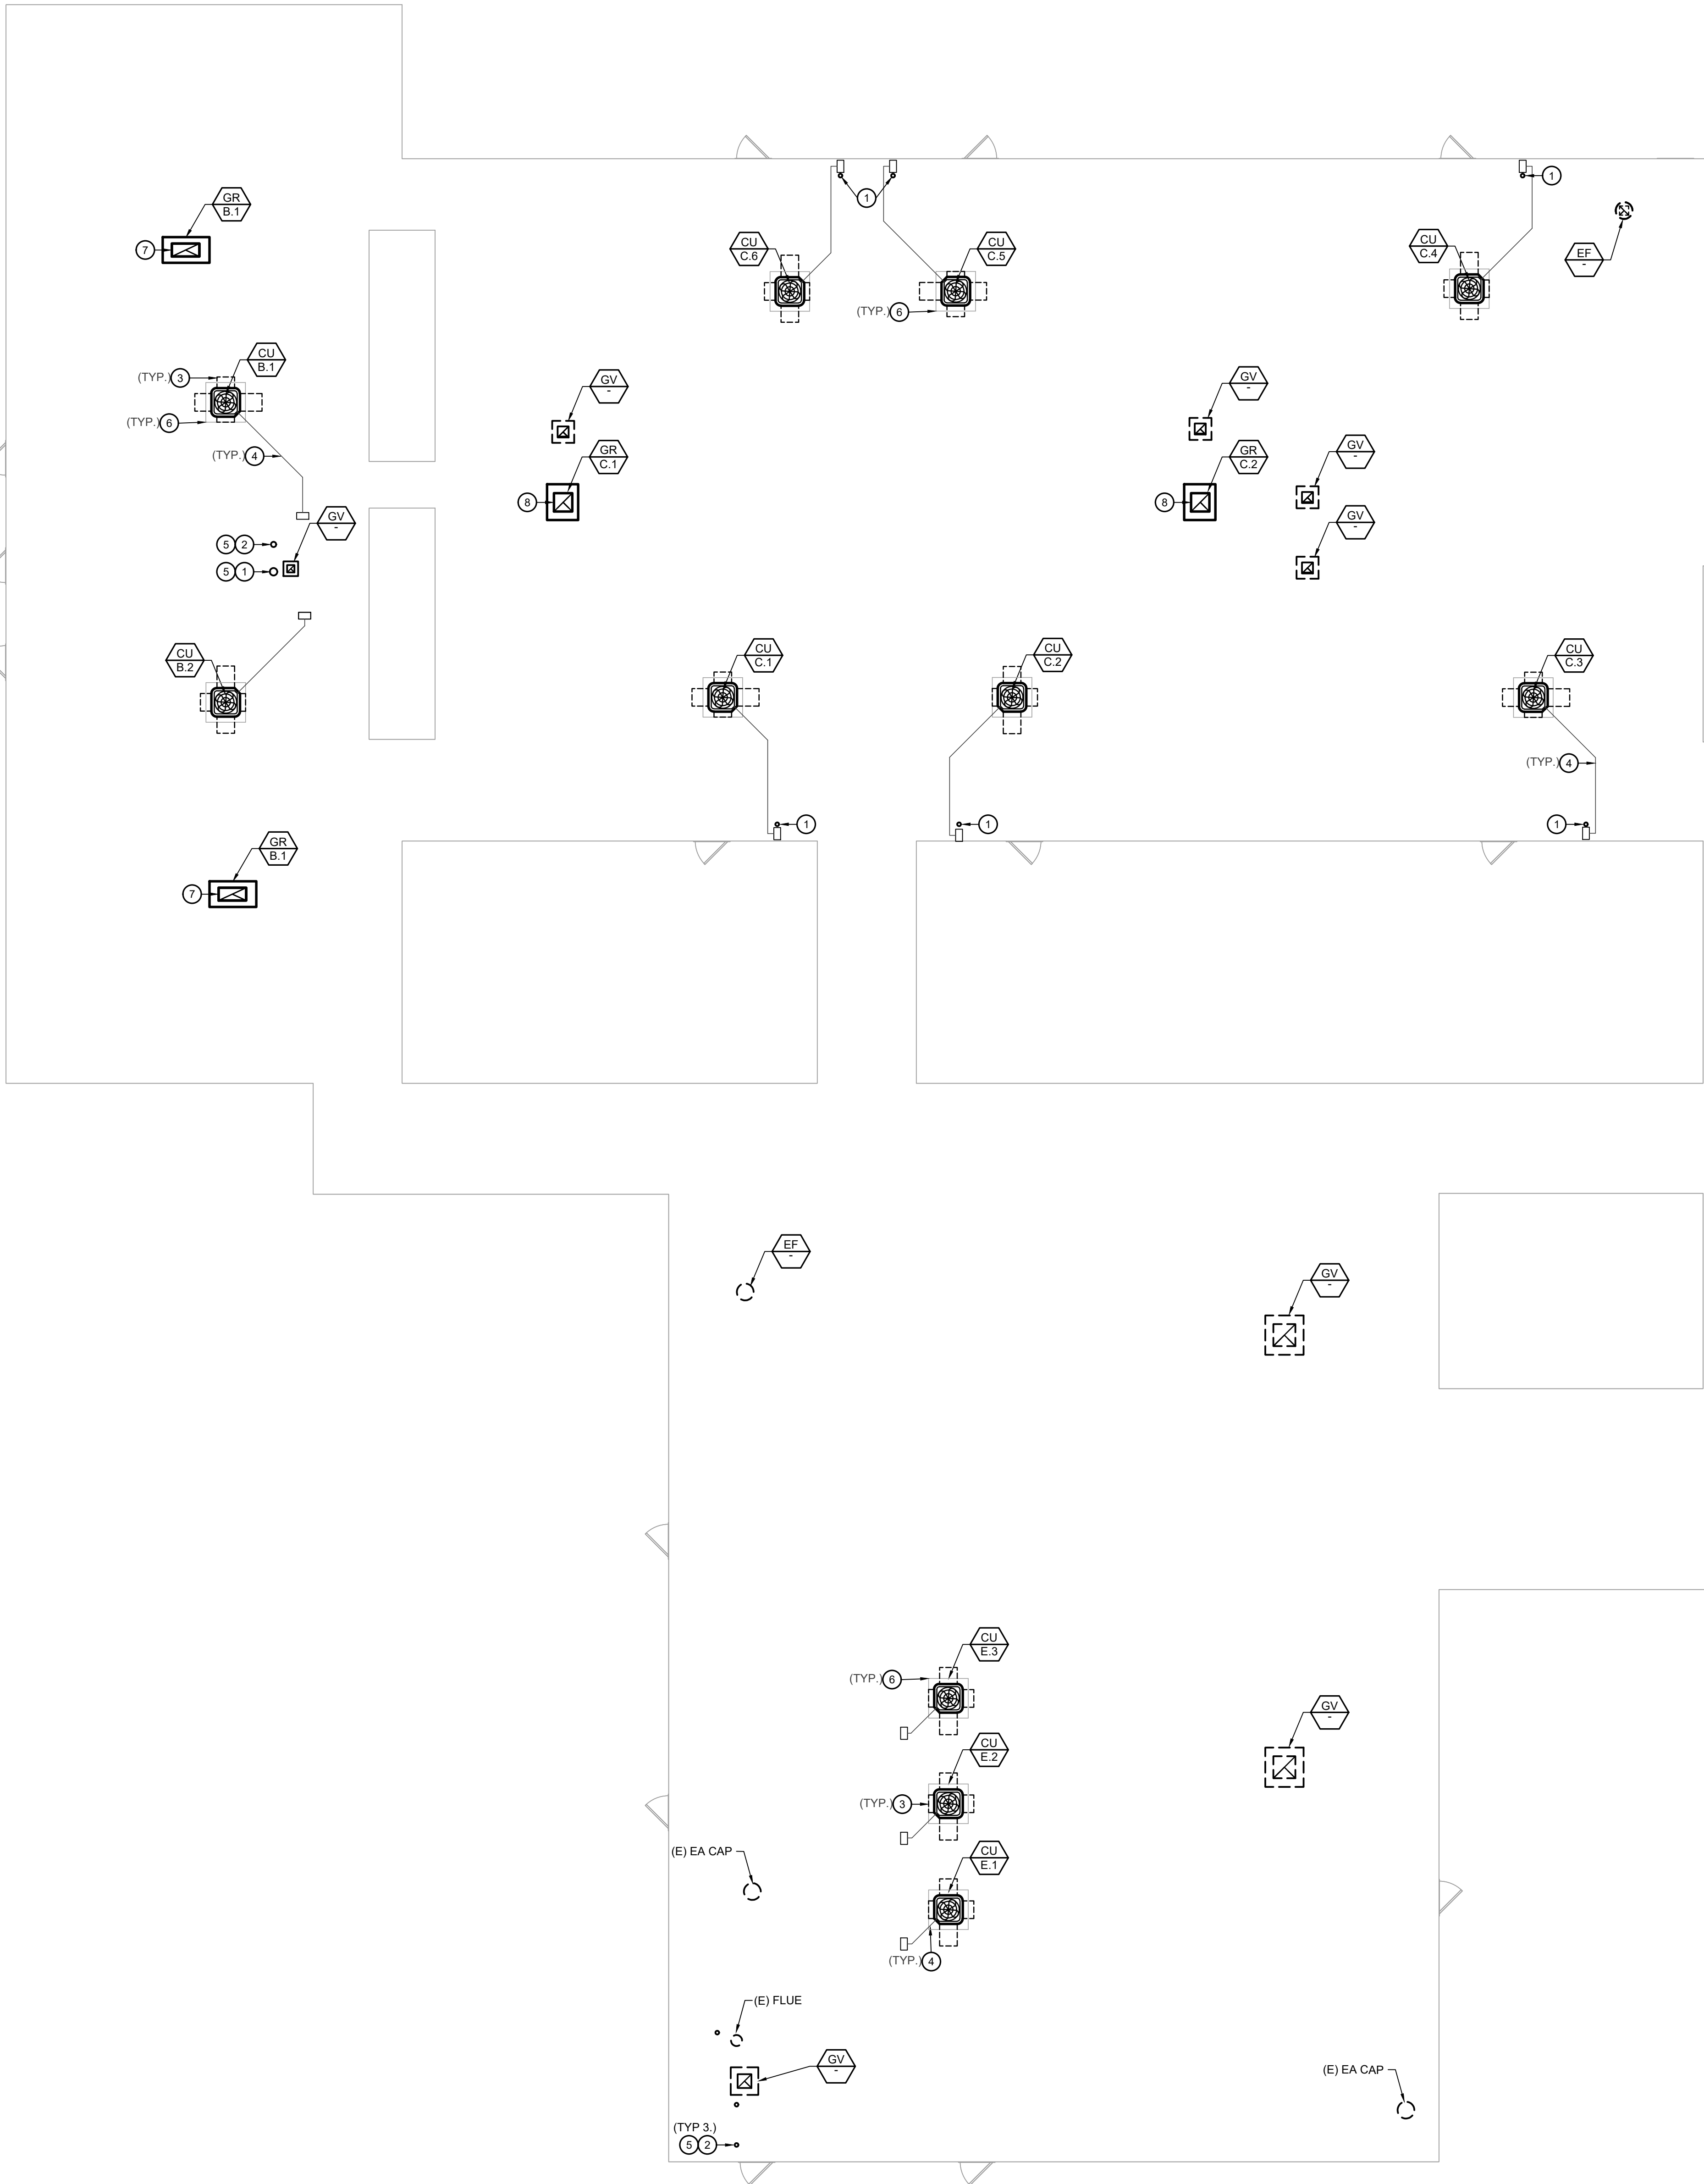


CONSTRUCTION GENERAL NOTES:

1. MAINTAIN MANUFACTURER'S MINIMUM CLEARANCES ON ALL MECHANICAL EQUIPMENT.
2. CONTRACTOR SHALL INSTALL PIPING SUCH THAT EQUIPMENT AND ALL APPURTENANCES ARE EASILY SERVICEABLE.
3. CONTRACTOR SHALL REUSE EXISTING OPENING(S) IN WALLS AND/OR ROOF FOR FUTURE PIPING AND ETC, WHEREVER POSSIBLE. COORDINATE WITH OTHER TRADES AS NECESSARY.
4. CONTRACTOR SHALL PATCH AND REPAIR EXISTING WALLS, FLOORS, CEILINGS, AND/OR ROOF OPENING(S) AS NECESSARY FOR EXISTING HVAC EQUIPMENT, DUCTS, PIPING, & ETC. BEING REMOVED. MATCH SURROUNDING MATERIAL AND MAINTAIN FIRE RATING.
5. CONTRACTOR SHALL INSULATE ALL REFRIGERANT PIPING LINES AND PROVIDE ALUMINUM WEATHER JACKETING FOR ALL OUTDOOR REFRIGERANT PIPING.
6. CONTRACTOR SHALL COORDINATE VENT, AND REFRIGERANT PIPE SIZES WITH MANUFACTURER REPRESENTATIVE(S) BASED UPON DETERMINATION OF ACTUAL IN FIELD DEVELOPED LENGTH PRIOR TO ORDERING PRODUCT.
7. ALL NEW GRAVITY HOODS DUCT DOWN THRU' ROOF SHALL FIT WITHIN EXISTING FRAMING. NO FRAMING SHALL BE CUT FOR NEW WORK INSTALLATION.
8. NO WALL OPENINGS ARE PERMITTED WITHOUT SEOR APPROVAL EXCEPT RE-USING EXISTING OPENINGS AND MODIFICATION TO EXISTING OPENINGS AS NOTED ON THESE PLANS AND DETAILS ON STRUCTURAL DRAWING S8.01.


CONSTRUCTION KEY NOTES:

- 1 NEW 3" CONCENTRIC VENT THRU' ROOF. RE-USE EXISTING ROOF OPENING AND MODIFY AS NECESSARY.
- 2 NEW 3" CONCENTRIC VENT THRU' ROOF.
- 3 OUTLINE OF NEW EQUIPMENT MINIMUM CLEARANCES.
- 4 NEW REFRIGERANT PIPING (RG & RL) DOWN THRU' ROOF WITHIN EXISTING ROOFTOP GOOSENECK. CONCEAL EXISTING GOOSENECK OPENING WITH SHEET METAL COVER AND WEATHERPROOF PIPE PENETRATIONS.
- 5 EXTEND NEW VENT OUTLET MIN. 3 FEET ABOVE ANY AIR INTAKES.
- 6 NEW MIN. 8" HIGH EQUIPMENT PLATFORM. EXTEND MIN 6" AROUND PERIMETER OF UNIT.
- 7 14"x30" RELIEF DUCT DOWN THRU' ROOF. RE-USE EXISTING ROOF OPENING. MODIFY AS NECESSARY.
- 8 20"x20" RELIEF DUCT DOWN THRU' ROOF. RE-USE EXISTING ROOF OPENING. MODIFY AS NECESSARY.

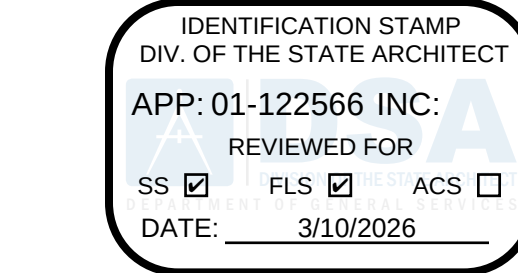

Revisions			
Delta	Date	Revisions	By

KEY PLAN

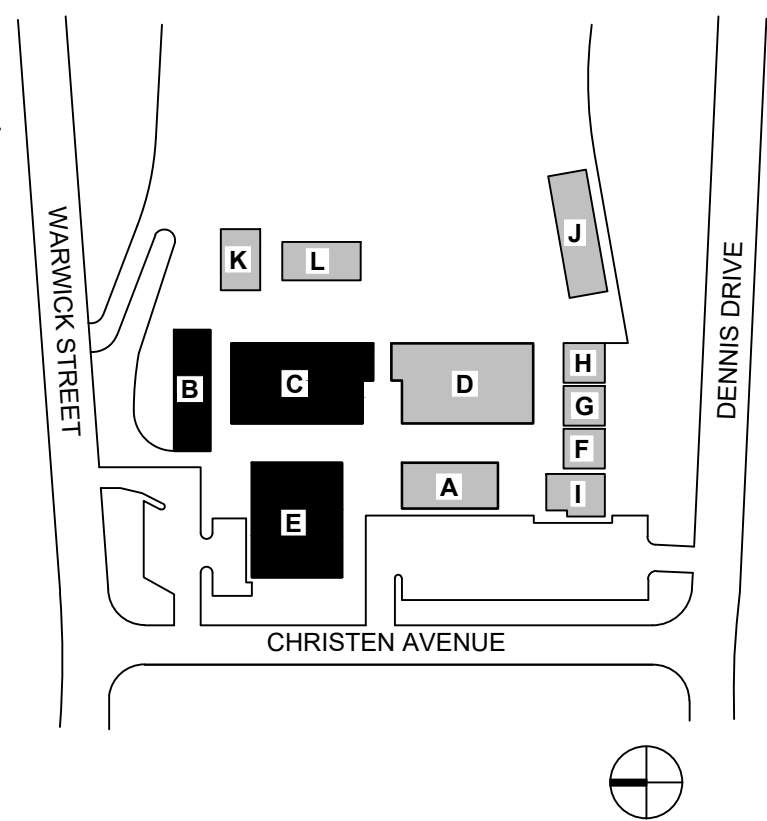

Consulting Engineers
5277 College Avenue
Oakland, CA 94618
Telephone (510) 837-9182

This document is the property of the Owner and is not to be used without their written permission



HY Architects Project number: Project Number

Facility
SKYLINE ELEMENTARY SCHOOL
55 CHRISTEN AVE, DALY CITY, CA 94015

Project
HVAC REPLACEMENT


Sheet Title
BUILDINGS B, C & E
MECHANICAL NEW WORK ROOF
PLAN

Client Project Number: 0000.0

Scale: As indicated
Drawn By: CC
Checked By: AK
Issue Date:
Revit Version: 2023

Sheet
M2.03
of

3/26/2023 3:12:50 PM M:\P - PROJECTS\20250502-25-001 SFUSD SKYLINE ES\02_MECH

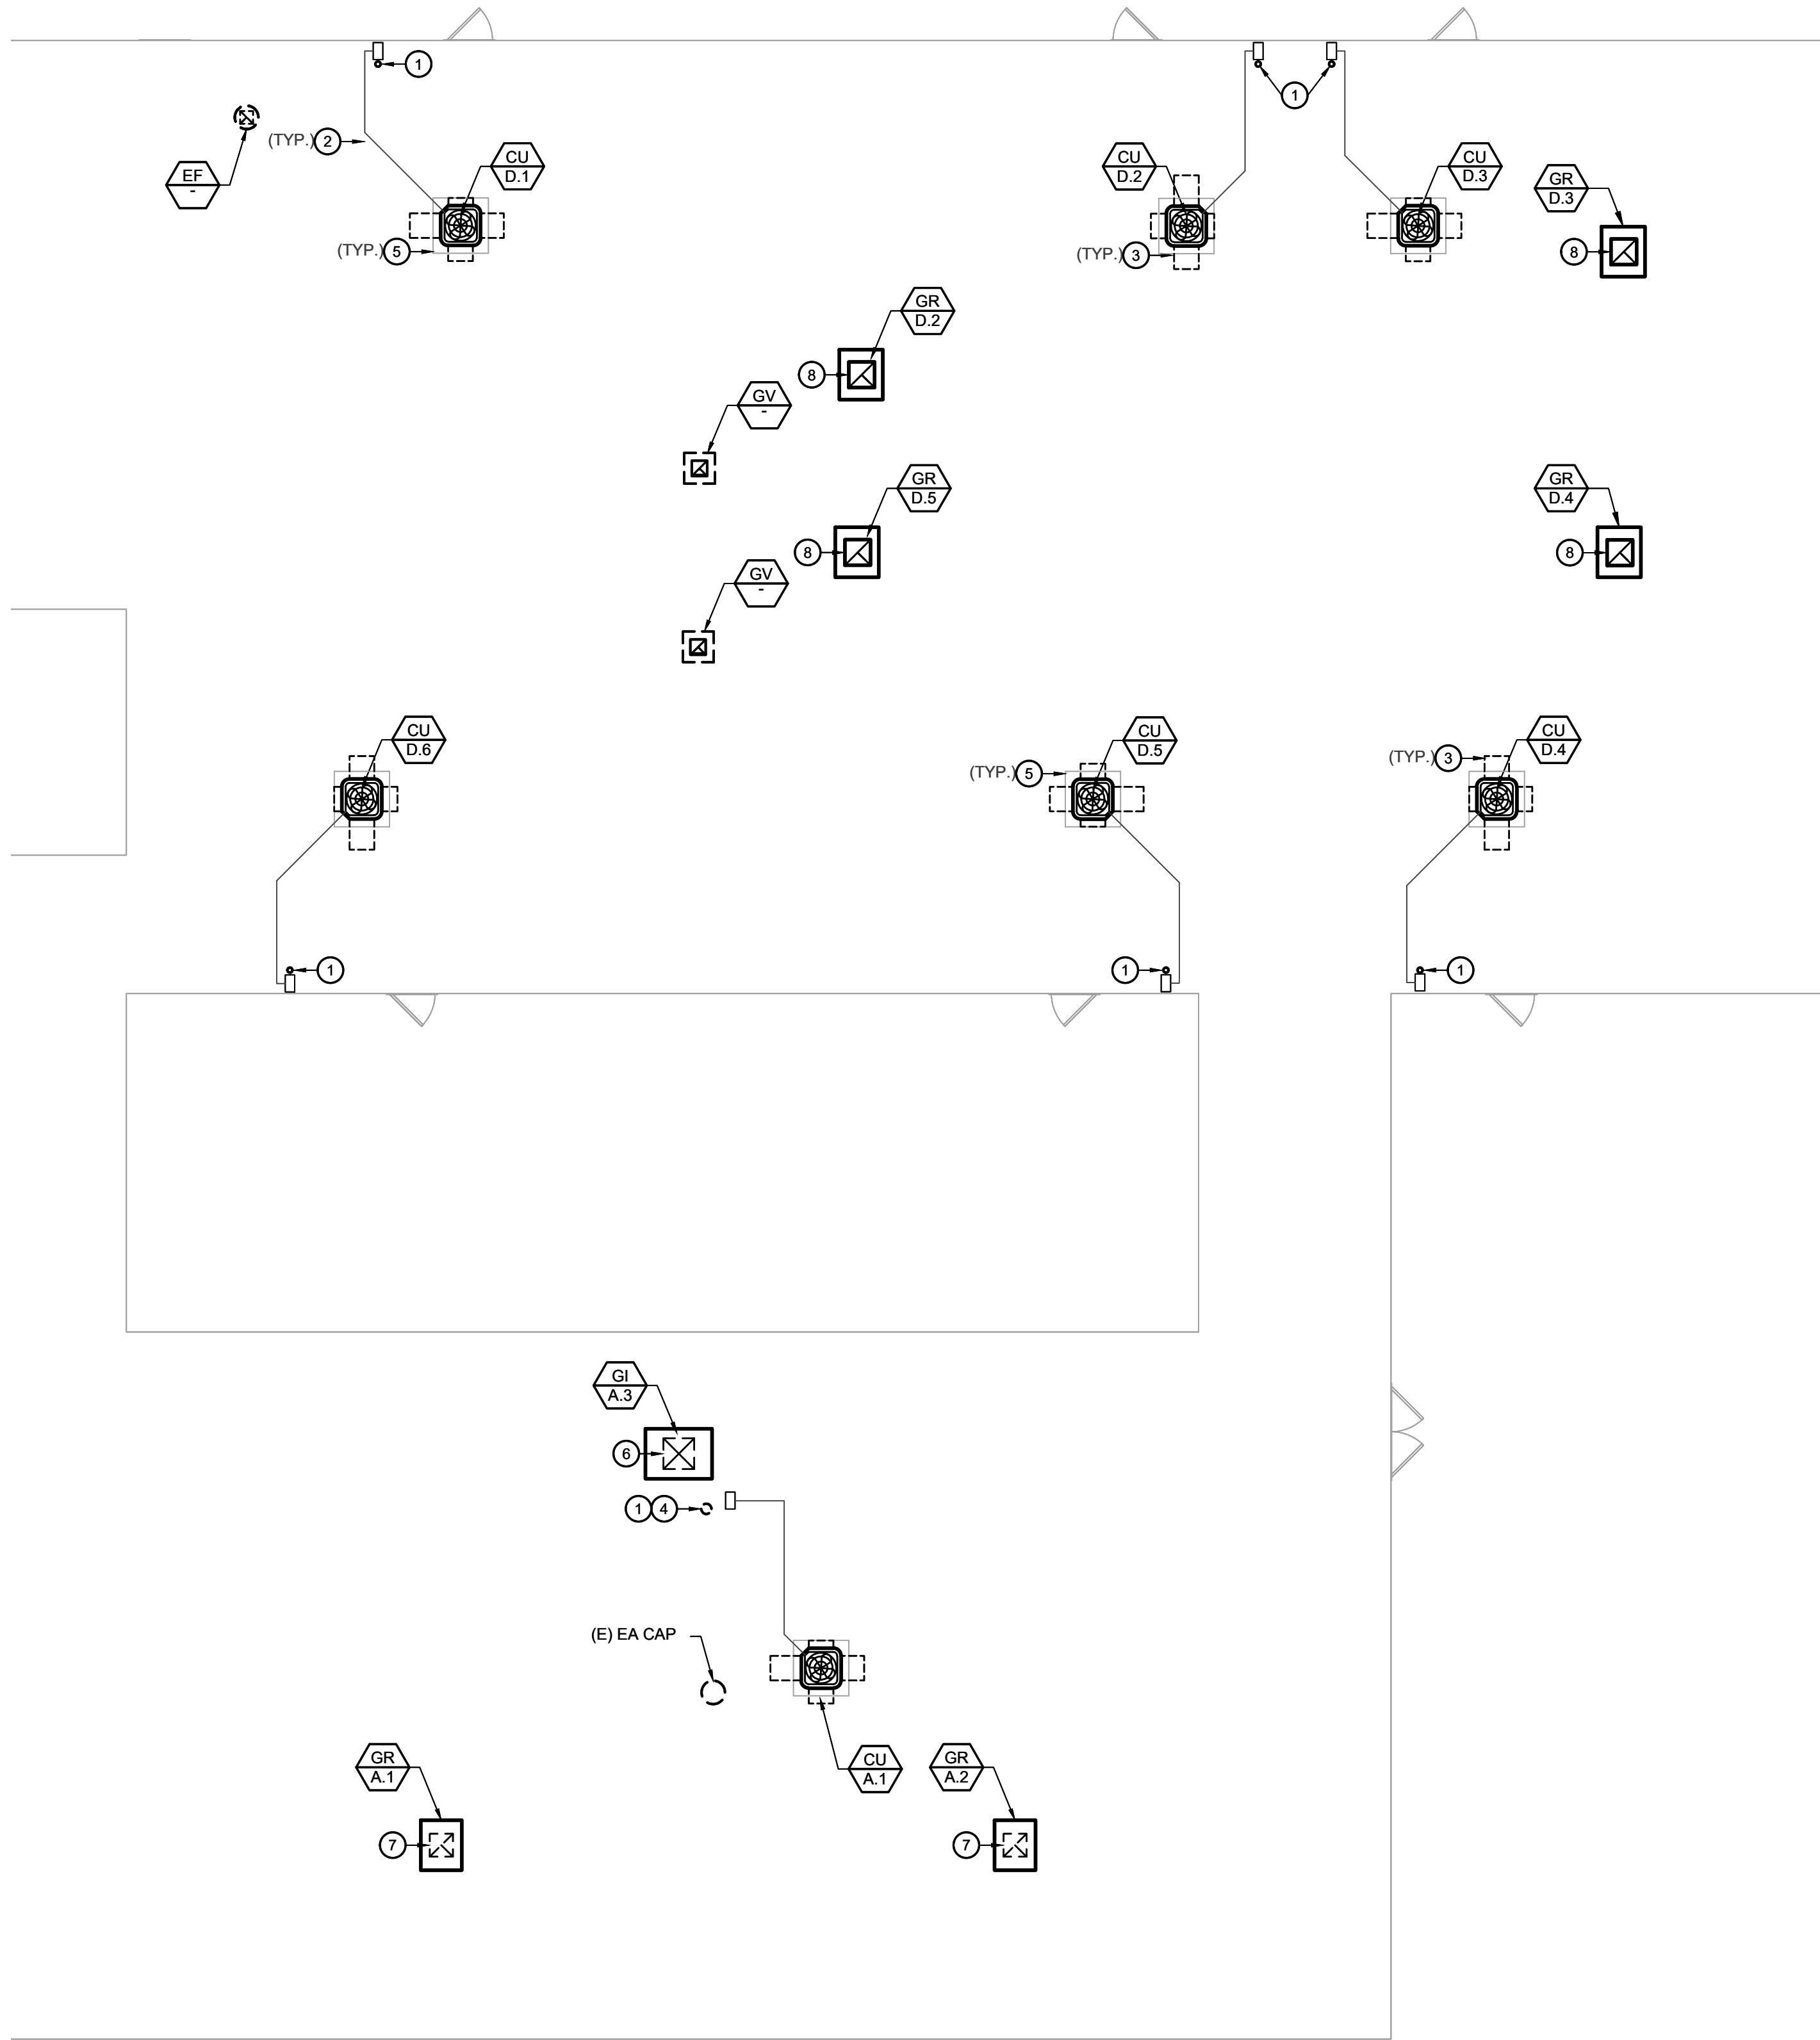


CONSTRUCTION GENERAL NOTES:

1. MAINTAIN MANUFACTURER'S MINIMUM CLEARANCES ON ALL MECHANICAL EQUIPMENT.
2. CONTRACTOR SHALL INSTALL PIPING SUCH THAT EQUIPMENT AND ALL APPURTENANCES ARE EASILY SERVICEABLE.
3. CONTRACTOR SHALL REUSE EXISTING OPENING(S) IN WALLS AND/OR ROOF FOR FUTURE PIPING AND ETC. WHEREVER POSSIBLE. COORDINATE WITH OTHER TRADES AS NECESSARY.
4. CONTRACTOR SHALL PATCH AND REPAIR EXISTING WALLS, FLOORS, CEILINGS, AND/OR ROOF OPENING(S) AS NECESSARY FOR EXISTING HVAC EQUIPMENT, DUCTS, PIPING, & ETC. BEING REMOVED. MATCH SURROUNDING MATERIAL AND MAINTAIN FIRE RATING.
5. CONTRACTOR SHALL INSULATE ALL REFRIGERANT PIPING LINES AND PROVIDE ALUMINUM WEATHER JACKETING FOR ALL OUTDOOR REFRIGERANT PIPING.
6. CONTRACTOR SHALL COORDINATE VENT, AND REFRIGERANT PIPE SIZES WITH MANUFACTURER REPRESENTATIVE(S) BASED UPON DETERMINATION OF ACTUAL IN FIELD DEVELOPED LENGTH PRIOR TO ORDERING PRODUCT
7. ALL NEW GRAVITY HOODS DUCT DOWN THRU' ROOF SHALL FIT WITHIN EXISTING FRAMING. NO FRAMING SHALL BE CUT FOR NEW WORK INSTALLATION.
8. NO WALL OPENINGS ARE PERMITTED WITHOUT SEOR APPROVAL EXCEPT RE-USING EXISTING OPENINGS AND MODIFICATION TO EXISTING OPENINGS AS NOTED ON THESE PLANS AND DETAILS ON STRUCTURAL DRAWING S8.01.


CONSTRUCTION KEY NOTES:

- ① NEW 3" CONCENTRIC VENT THRU' ROOF. RE-USE EXISTING ROOF OPENING AND MODIFY AS NECESSARY.
- ② NEW REFRIGERANT PIPING (RG & RL) DOWN THRU' ROOF WITHIN EXISTING ROOFTOP GOOSENECK. CONCEAL EXISTING GOOSENECK OPENING WITH SHEET METAL COVER AND WEATHERPROOF PIPE PENETRATIONS.
- ③ OUTLINE OF NEW EQUIPMENT MINIMUM CLEARANCES.
- ④ EXTEND VENT OUTLET MIN. 3 FEET ABOVE AIR INTAKE.
- ⑤ NEW MIN. 8" HIGH EQUIPMENT PLATFORM. EXTEND MIN 6" AROUND PERIMETER OF UNIT.
- ⑥ 24"x24" OSA DUCT DOWN THRU' ROOF. RE-USE EXISTING ROOF OPENING. MODIFY AS NECESSARY.
- ⑦ 18"x18" RELIEF DUCT DOWN THRU' ROOF.
- ⑧ 20"x20" RELIEF DUCT DOWN THRU' ROOF. RE-USE EXISTING ROOF OPENING. MODIFY AS NECESSARY.

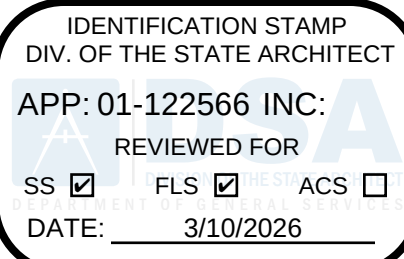

Revisions			
Delta	Date	Revisions	By

KEY PLAN

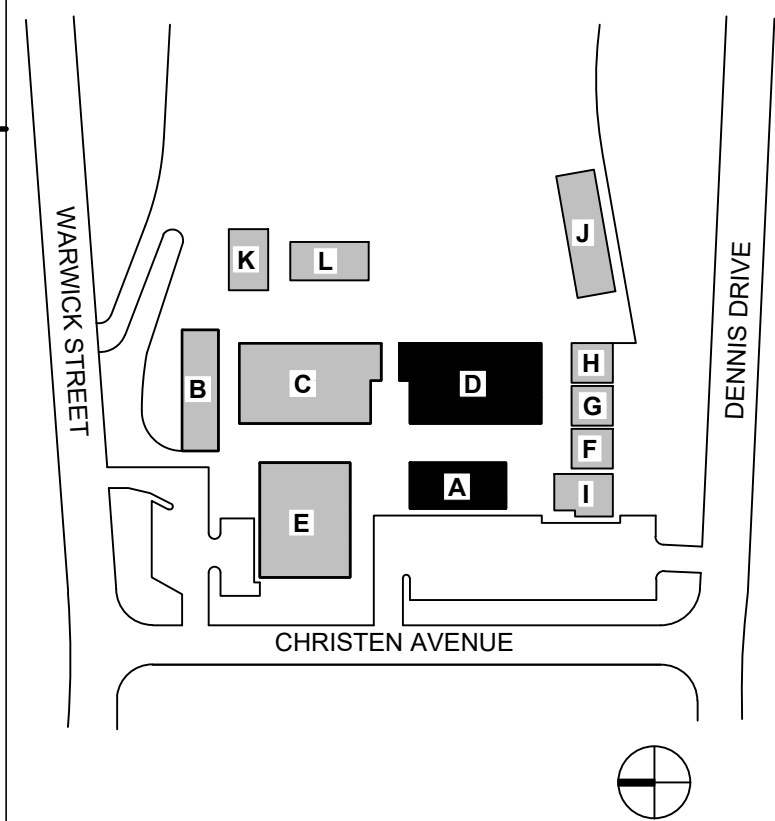

Consulting Engineers
5277 College Avenue
Oakland, CA 94618
Telephone (510) 837-9182

This document is the property of the Owner and is not to be used without their written permission



HY Architects Project number: Project Number

Facility
SKYLINE ELEMENTARY SCHOOL
55 CHRISTEN AVE, DALY CITY, CA 94015

Project
HVAC REPLACEMENT

Sheet Title
BUILDINGS A & D MECHANICAL
NEW WORK ROOF PLAN

Client Project Number: 0000.0


Scale:	As indicated	Sheet
Drawn By:	CC	
Checked By:	AK	
Issue Date:		
Revit Version: 2023		

M2.04
Sheet of

GRAVITY OUTSIDE-AIR INTAKE / RELIEF DETAIL

SCALE
NONE

1

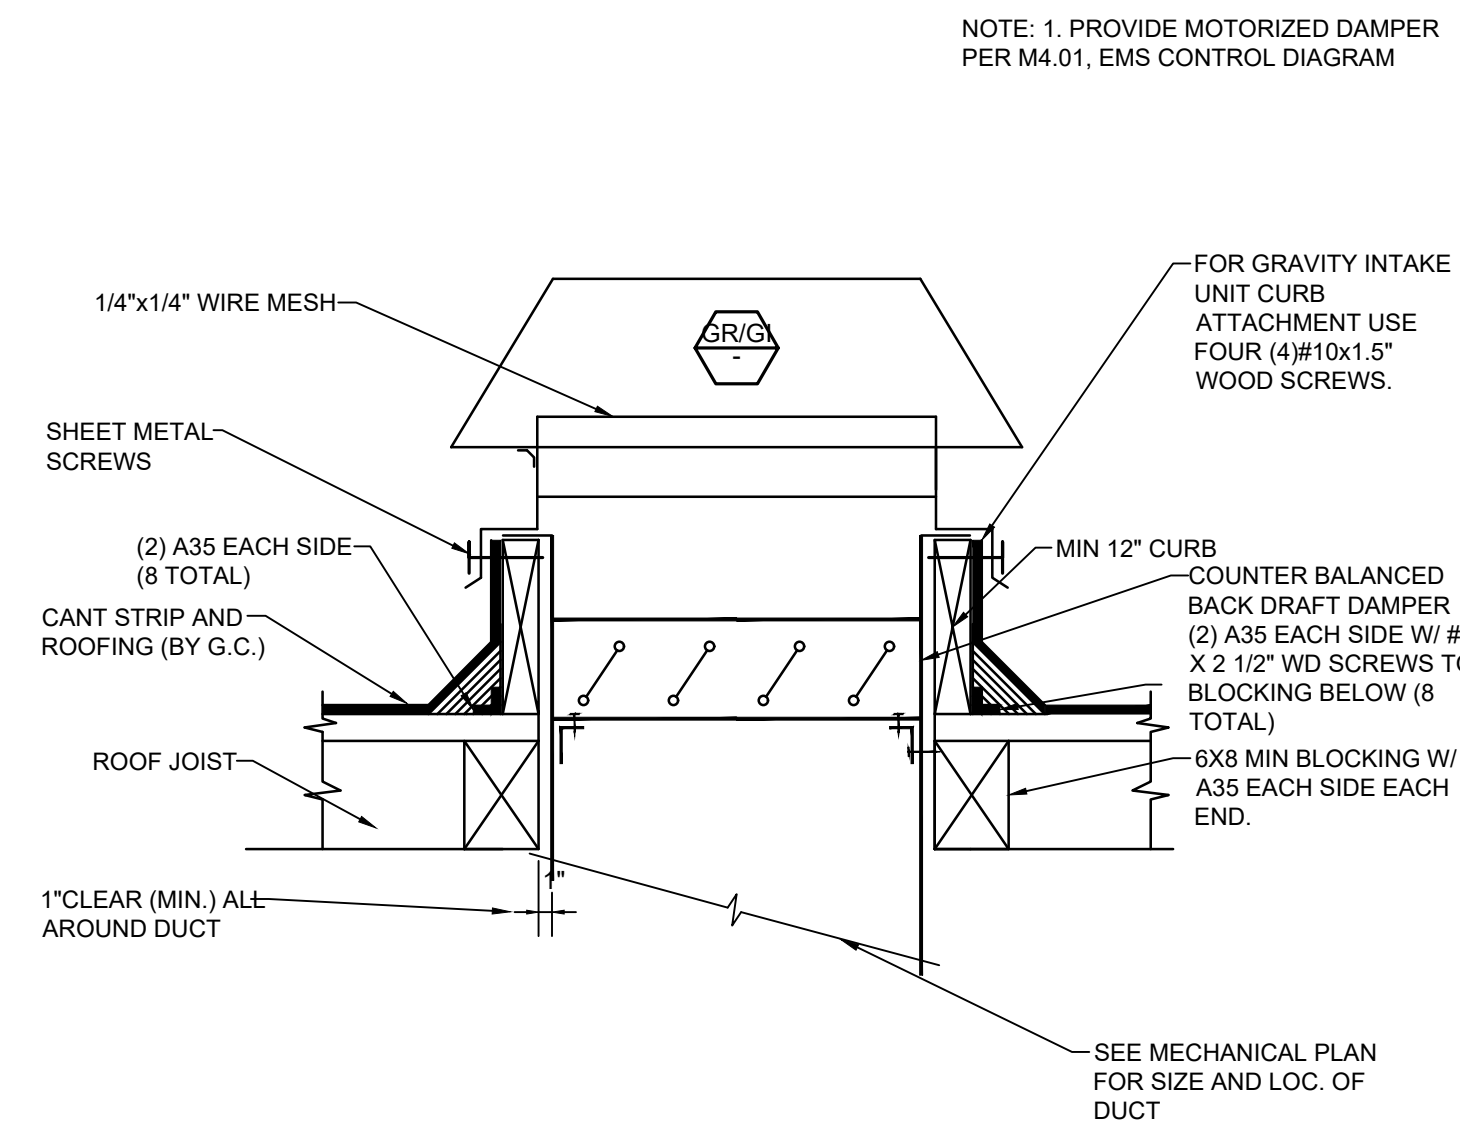


BUILDINGS A & D MECHANICAL NEW WORK ROOF PLAN

1/8" = 1'-0"

1










PIPE SUPPORT BRACING / SPACING SCHEDULE		
TYPE OF PIPE	SIZE	MAX.SPACING
COPPER	3/4" AND SMALLER	5 FT.
	1" TO 1-1/4"	6 FT.




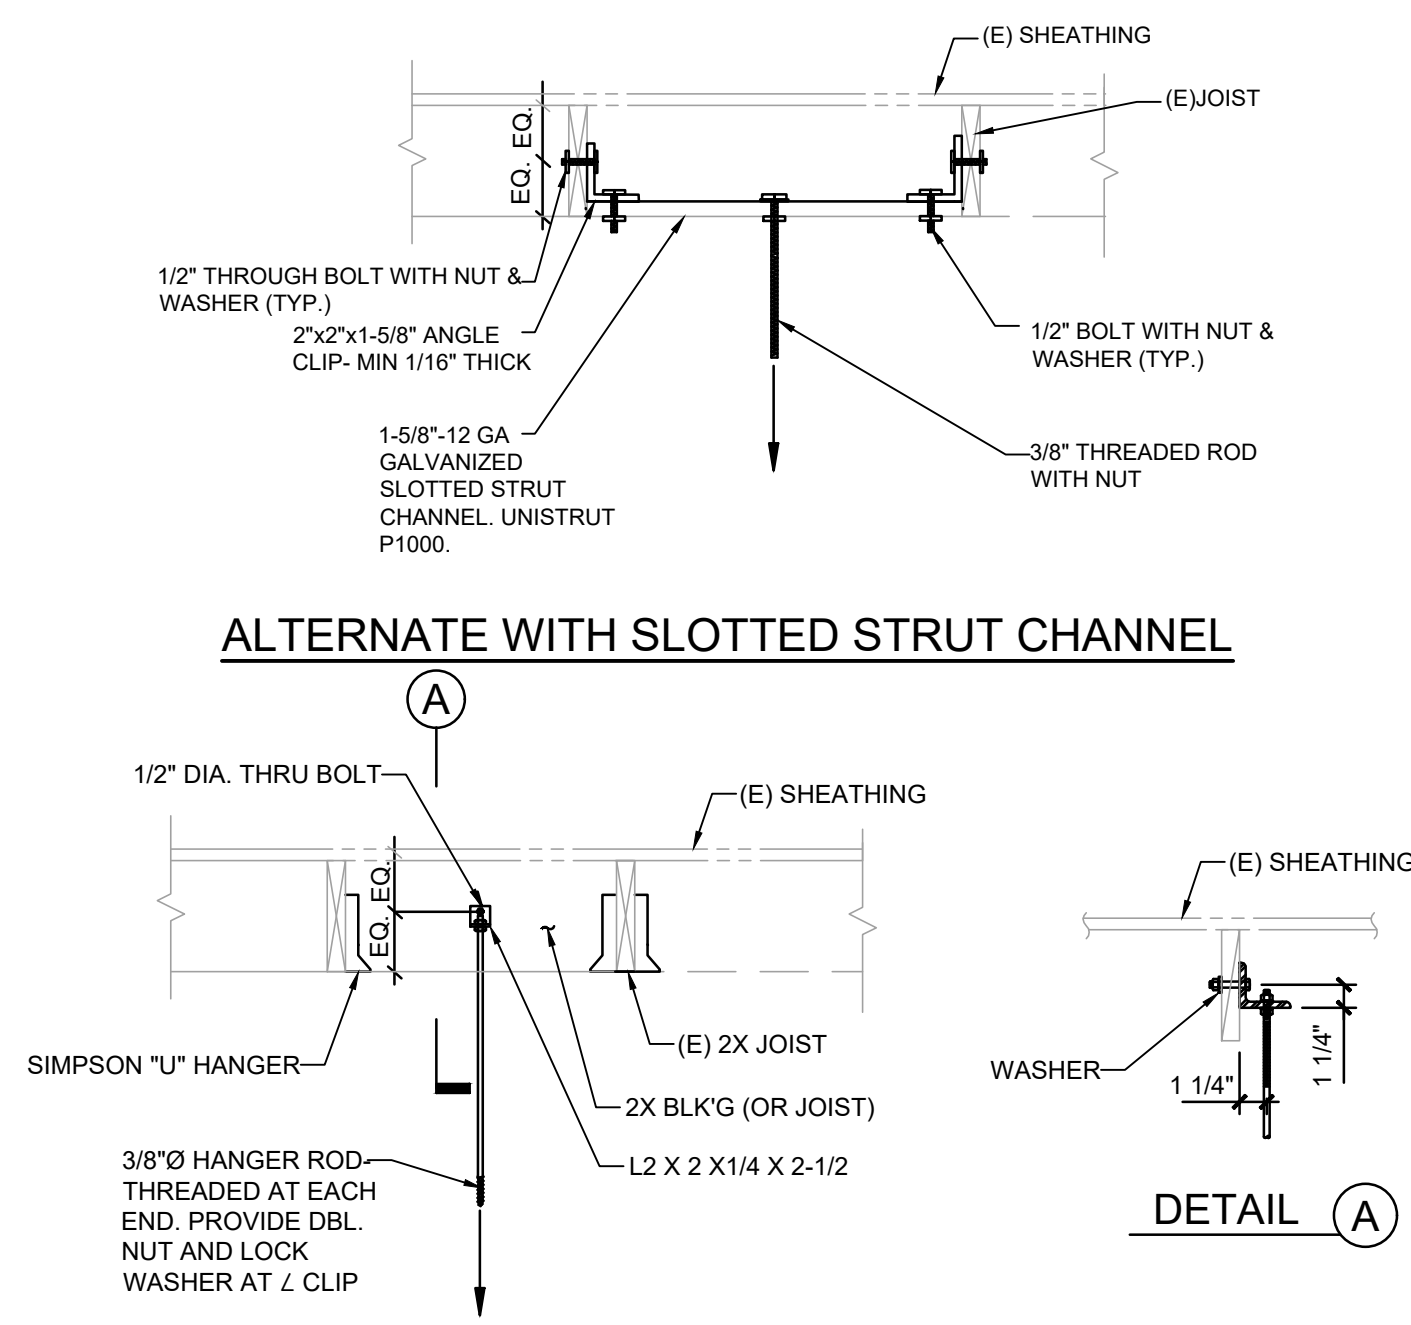


SCHEDULE FOR SINGLE PIPE HANGERS 3/4" THRU 1-1/8"		
PIPE SIZE	ROD SIZE	MAXIMUM LOAD (LBS PER FOOT)
3/4" THRU 1-1/8"	3/8"	2



- NOTES:**
1. SUPPORT PIPE HANGERS FROM STRUCTURAL BEAM ONLY.
 2. STRUCTURAL STEEL PENETRATIONS SHALL BE FIRST REVIEWED AND APPROVED BY THE STRUCTURAL ENGINEER (IF APPLICABLE)
 3. HANGER AND ROD SHALL BE DIPPED IN ZINC CHROMATE PRIMER PRIOR TO INSTALLATION.
 4. SCHEDULED DATA MAY ALSO BE USED FOR TRAPEZE HANGER SELECTION WITH EACH ROD NOT TO EXCEED THE LOADS SHOWN IN THE MAXIMUM LOAD COLUMN.
 5. FOR THE MAXIMUM HANGING ALLOWED IN THE STRUCTURE REFER TO STRUCTURAL DETAILS.
 6. BRACING FOR INDIVIDUALLY SUPPORTED PIPING SYSTEM MAY BE OMITTED WHEN ALL OF THE FOLLOWING CONDITIONS ARE MET:
 - VERTICAL SUPPORT IS PROVIDED BY ROD HANGERS.
 - NOMINAL PIPE SIZE DOES NOT EXCEED 2" FOR IP = 1.0 AND SEISMIC DESIGN CATEGORY C
 - PROVISIONS ARE MADE TO AVOID IMPACT WITH OTHER STRUCTURAL AND NON-STRUCTURAL COMPONENTS OR TO PROTECT THE PIPING IN THE EVENT OF AN IMPACT. THE SEPARATION DISTANCE BETWEEN THE UNBRACED COMPONENT AND OTHER COMPONENTS SHALL BE A MINIMUM OF 18 INCHES.

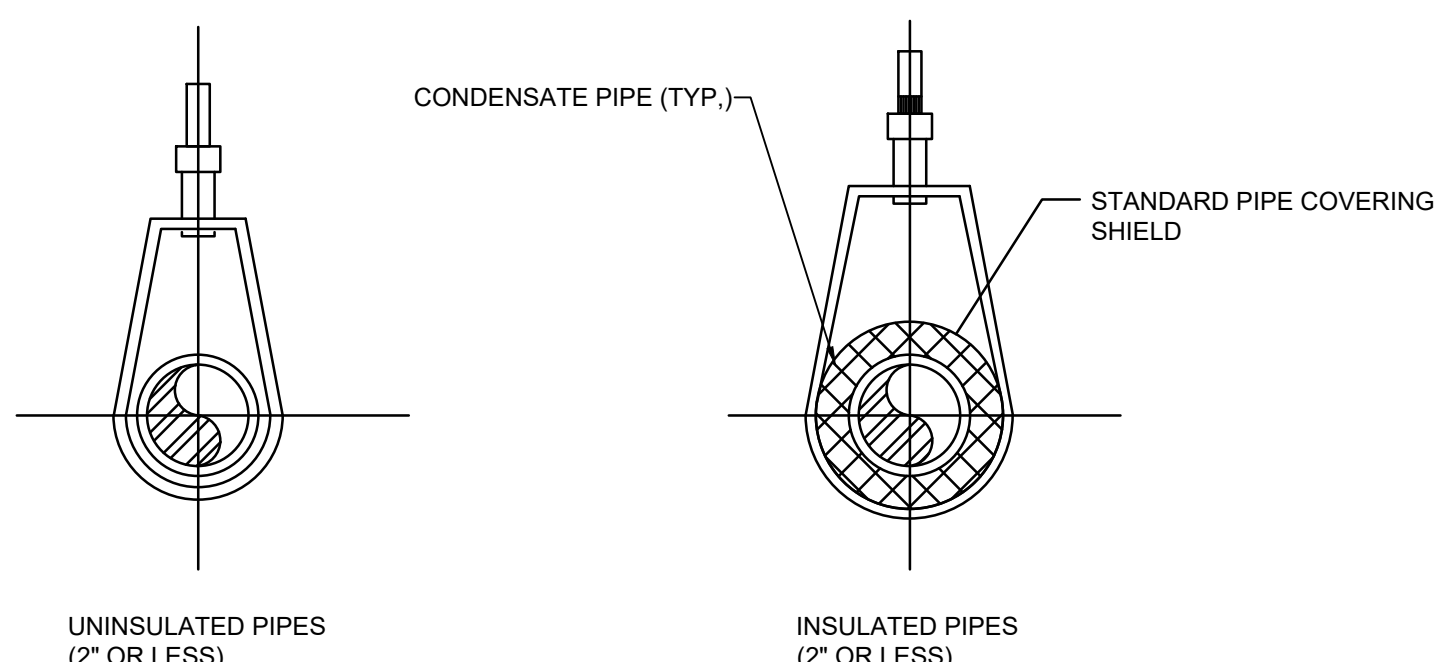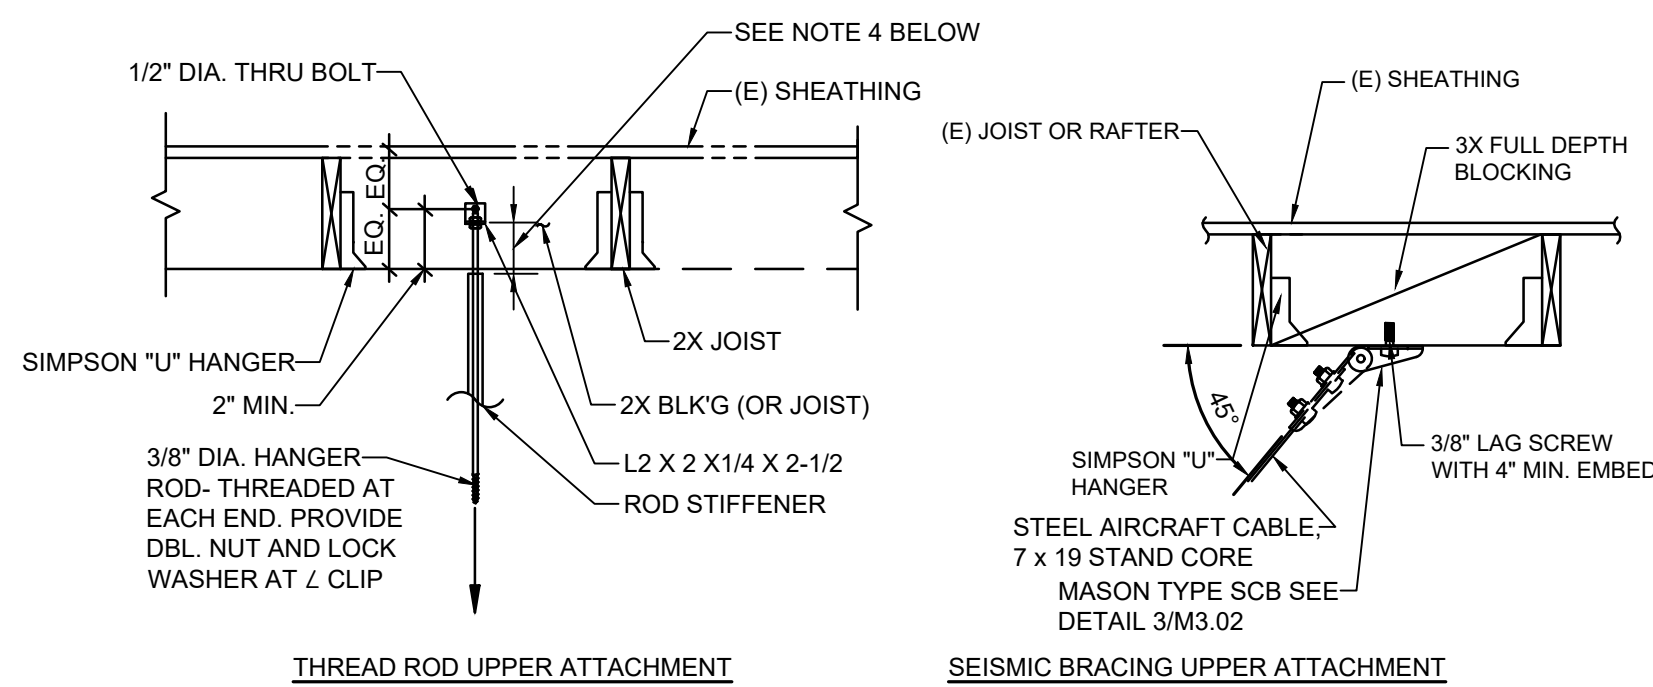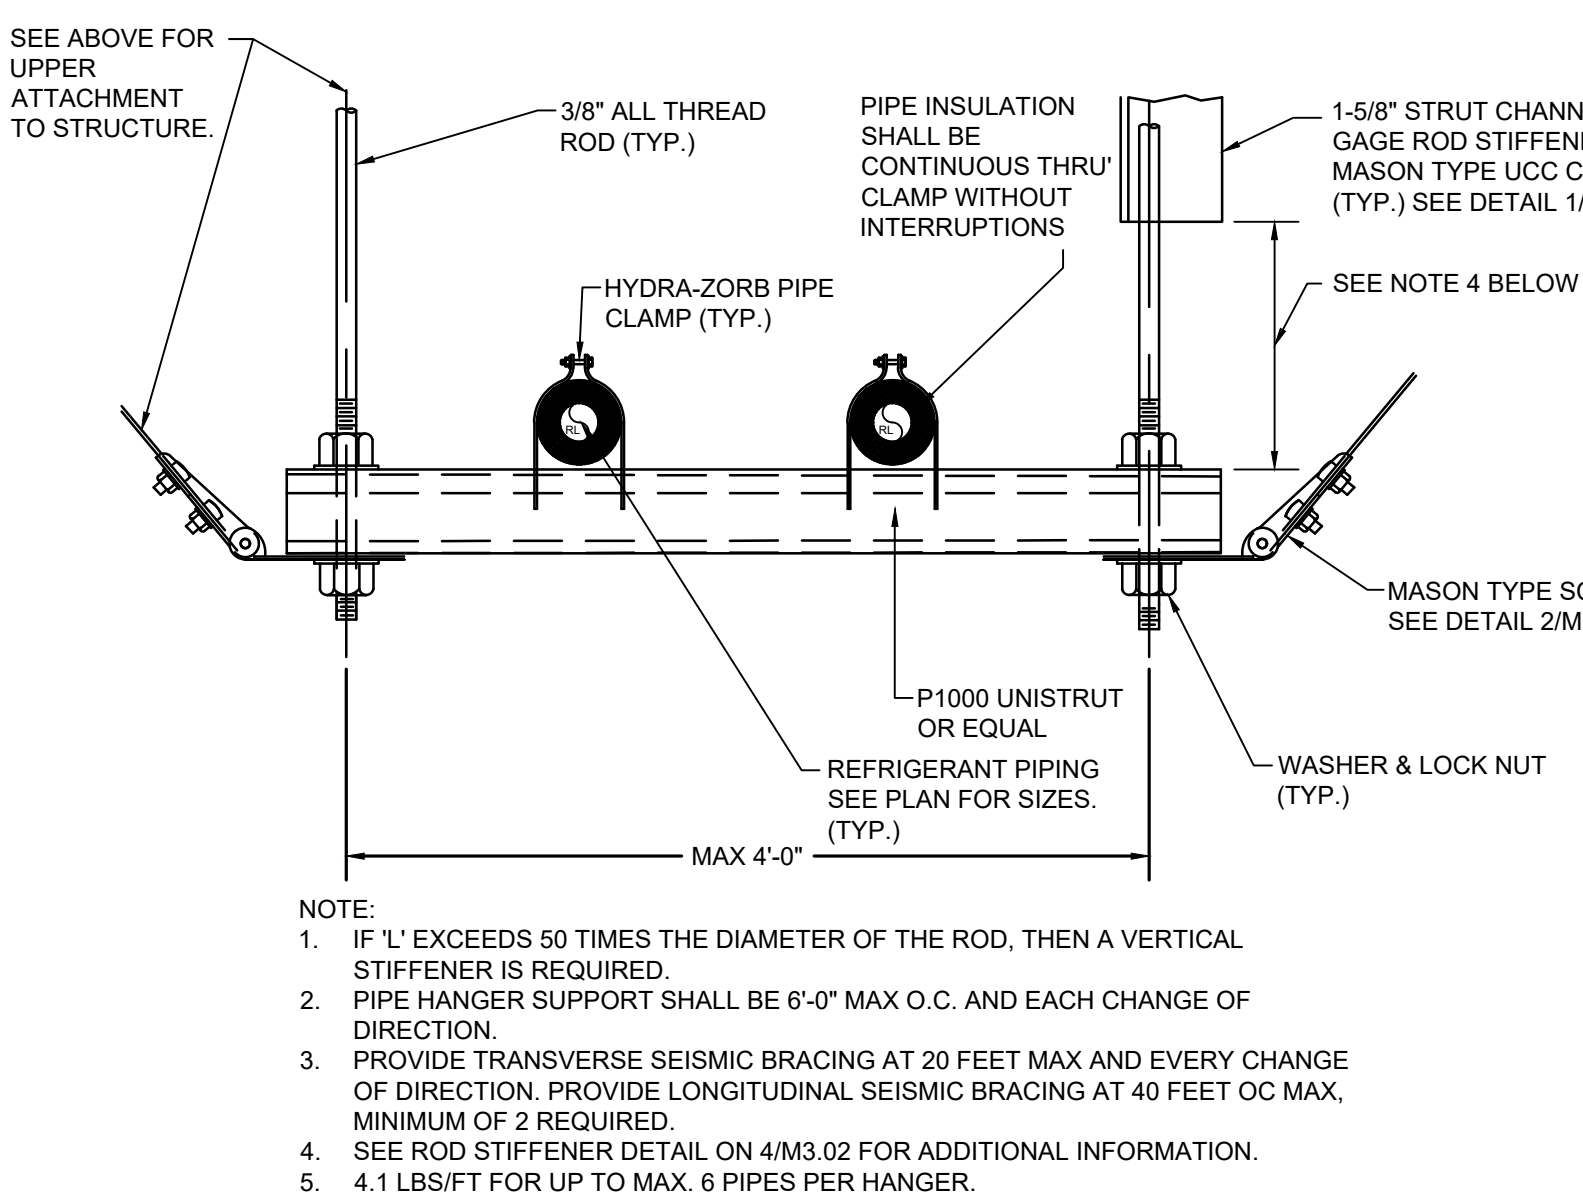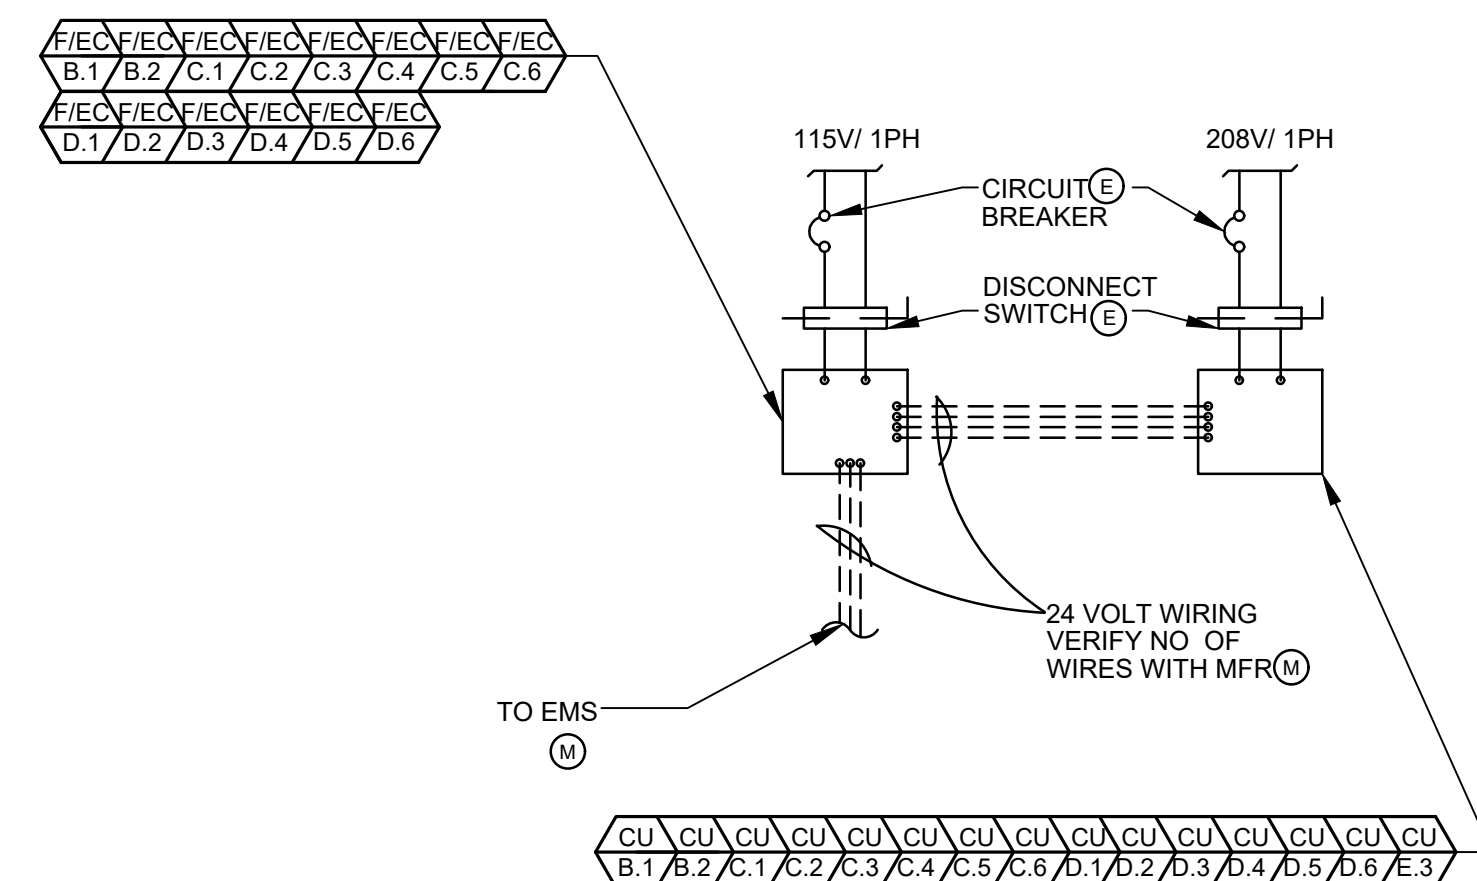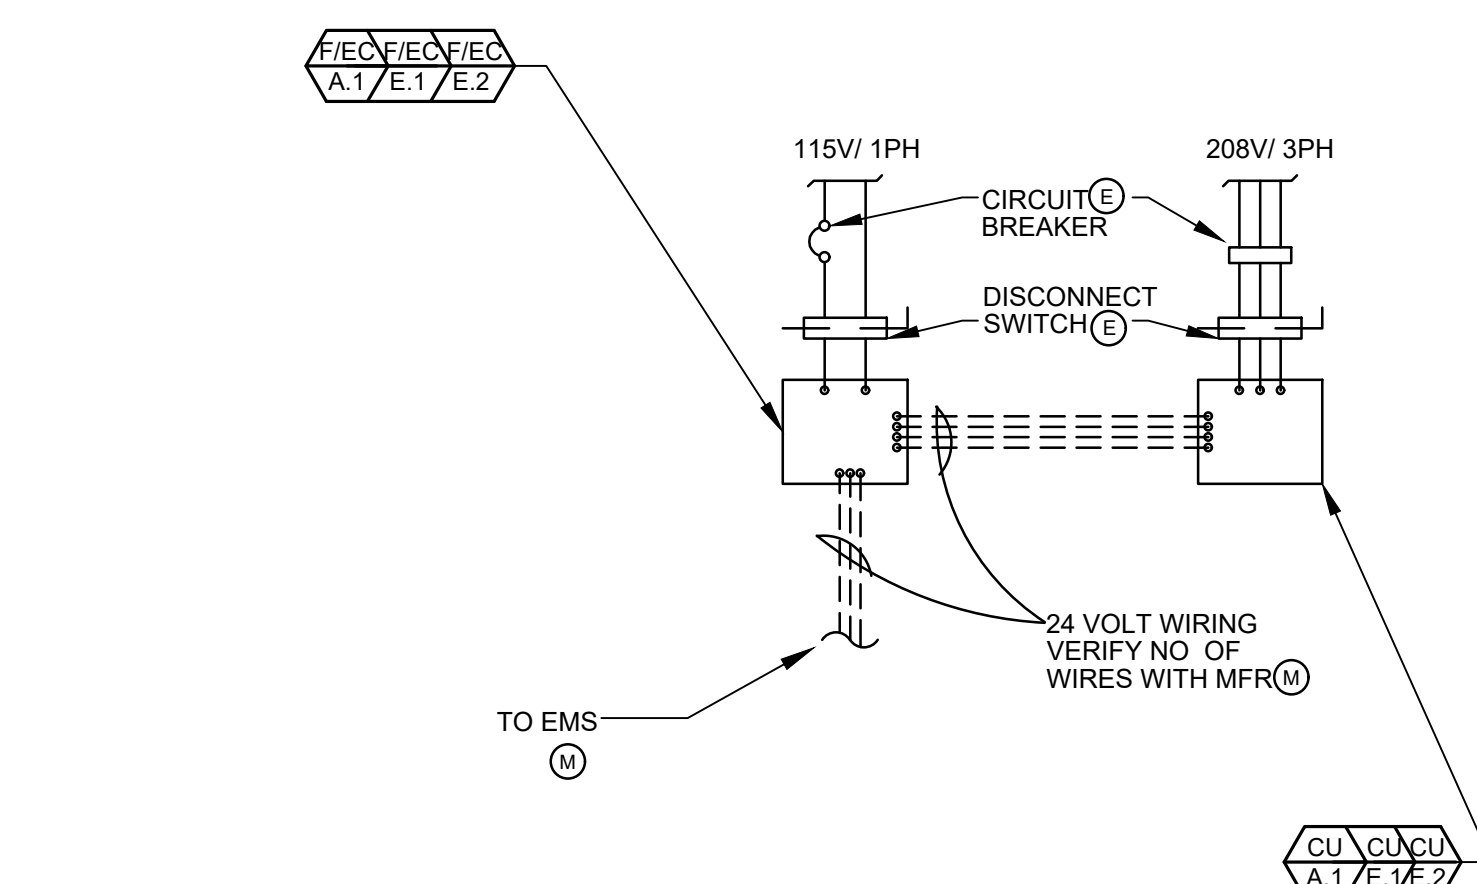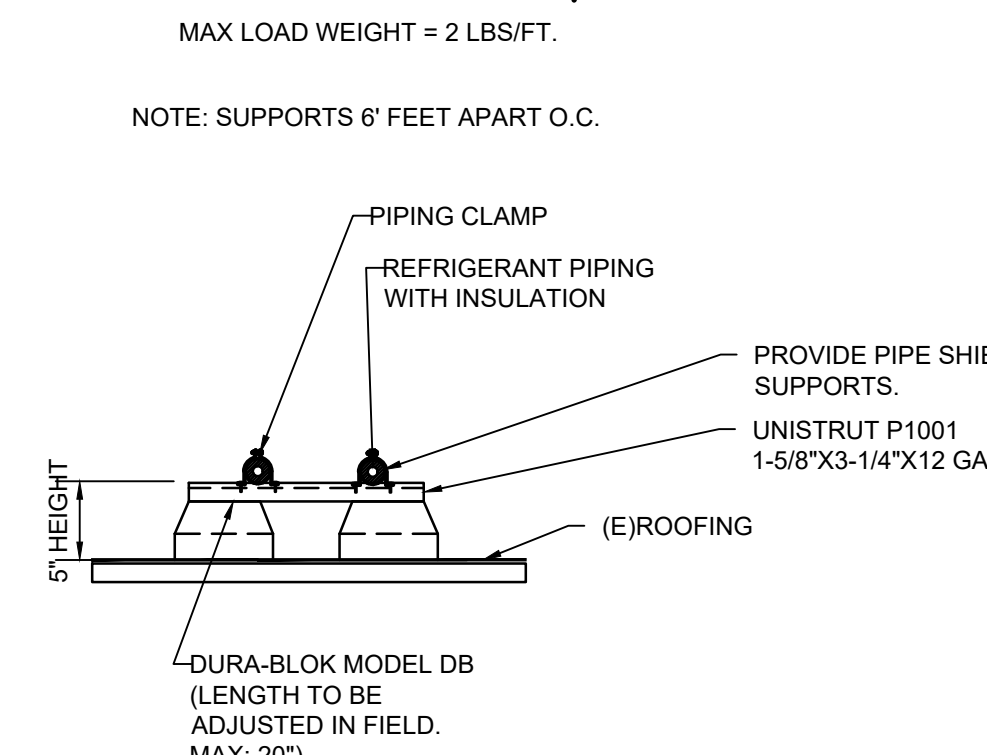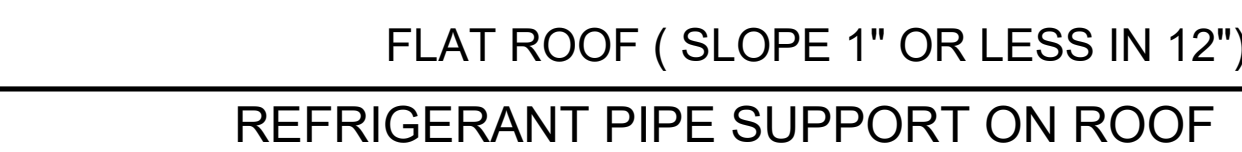

- NOTE:
PROVIDE SECONDARY DRAIN PAN W/FLOAT SWITCH
24V TO SHUT OFF UNIT PROTECTION OF OVERFLOW
PROVIDE AQUA GUARD MODEL AG-1200 OR
APPROVED EQUAL.

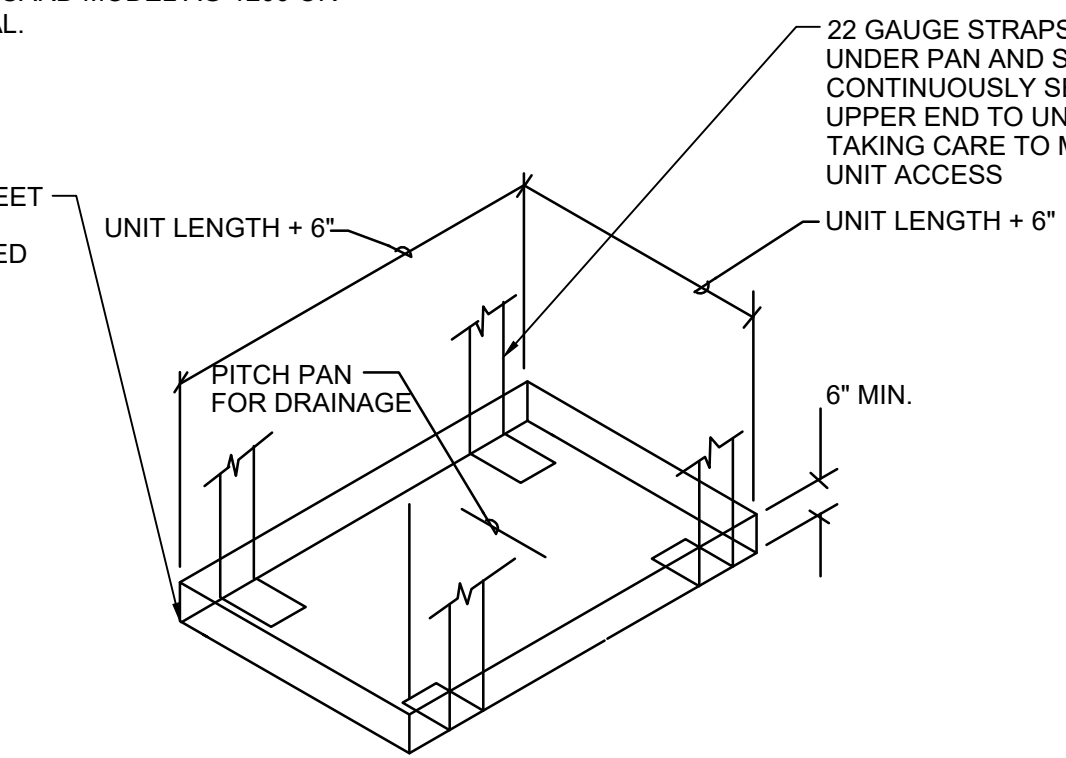
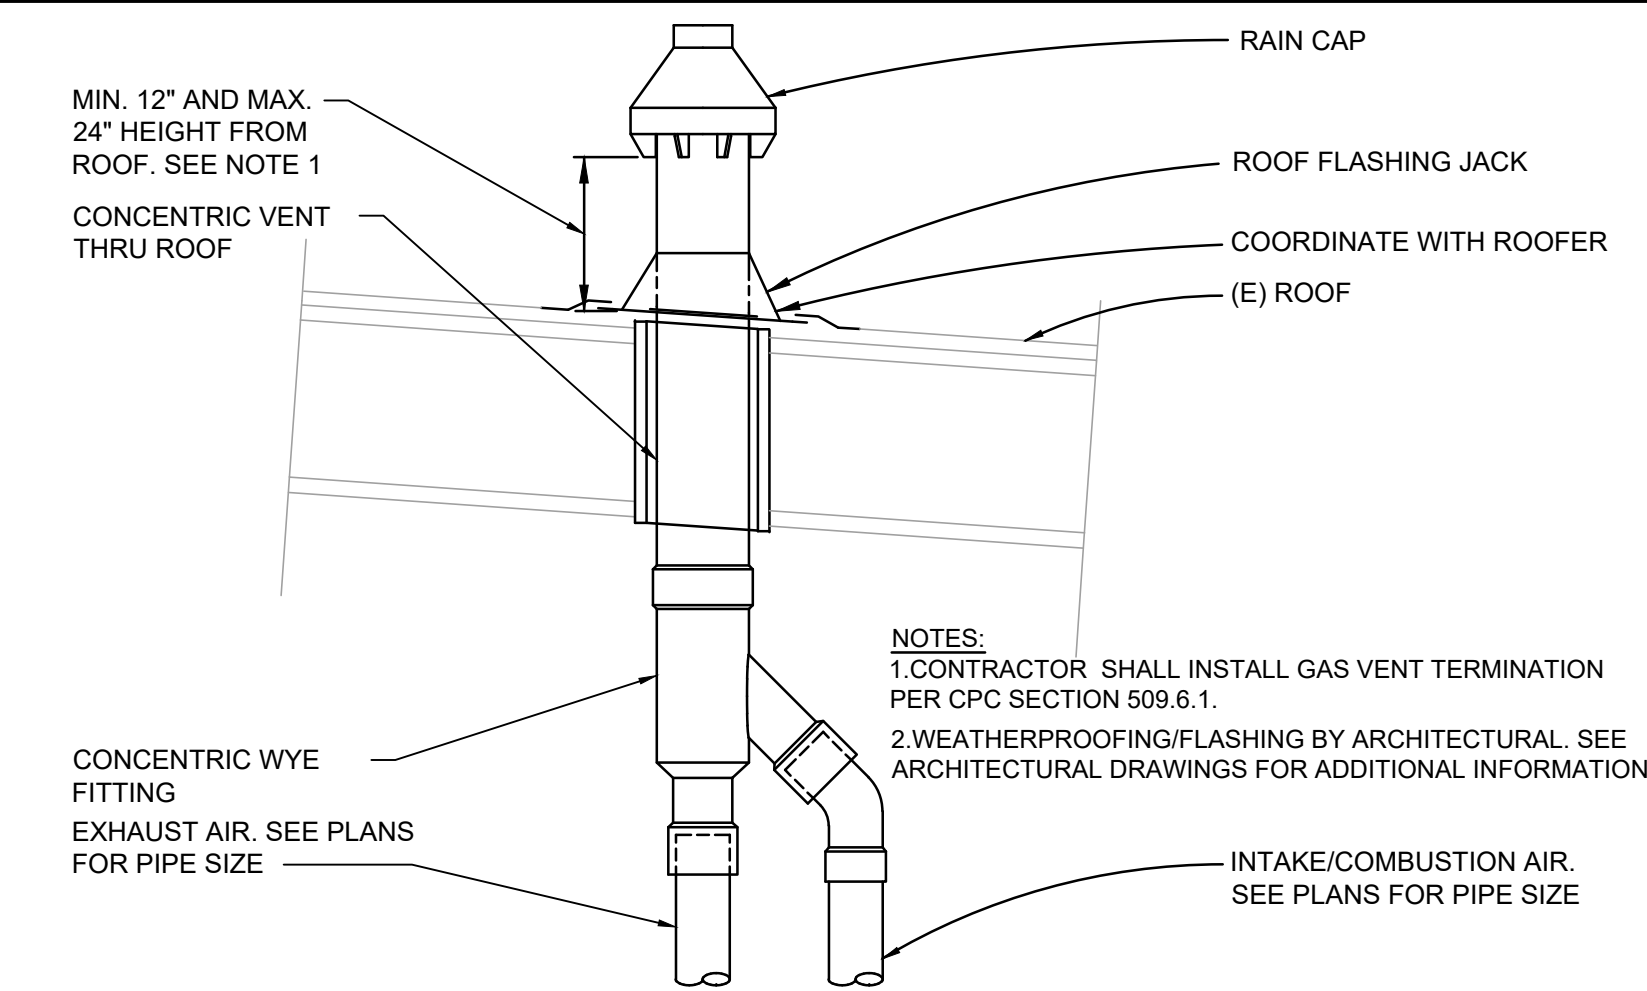
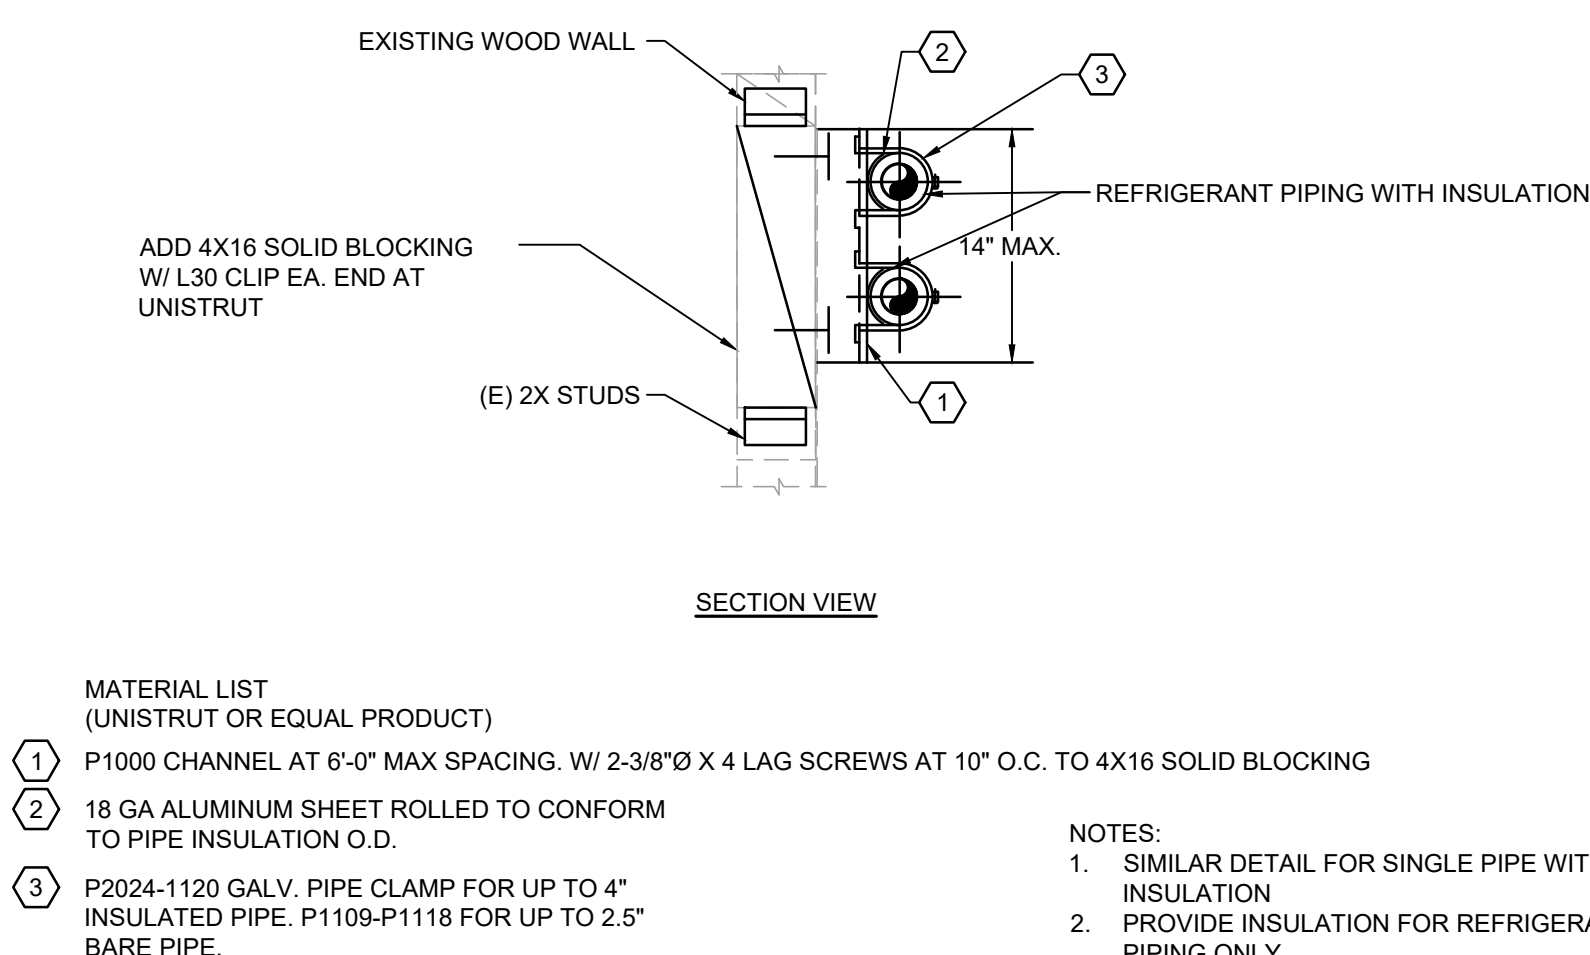
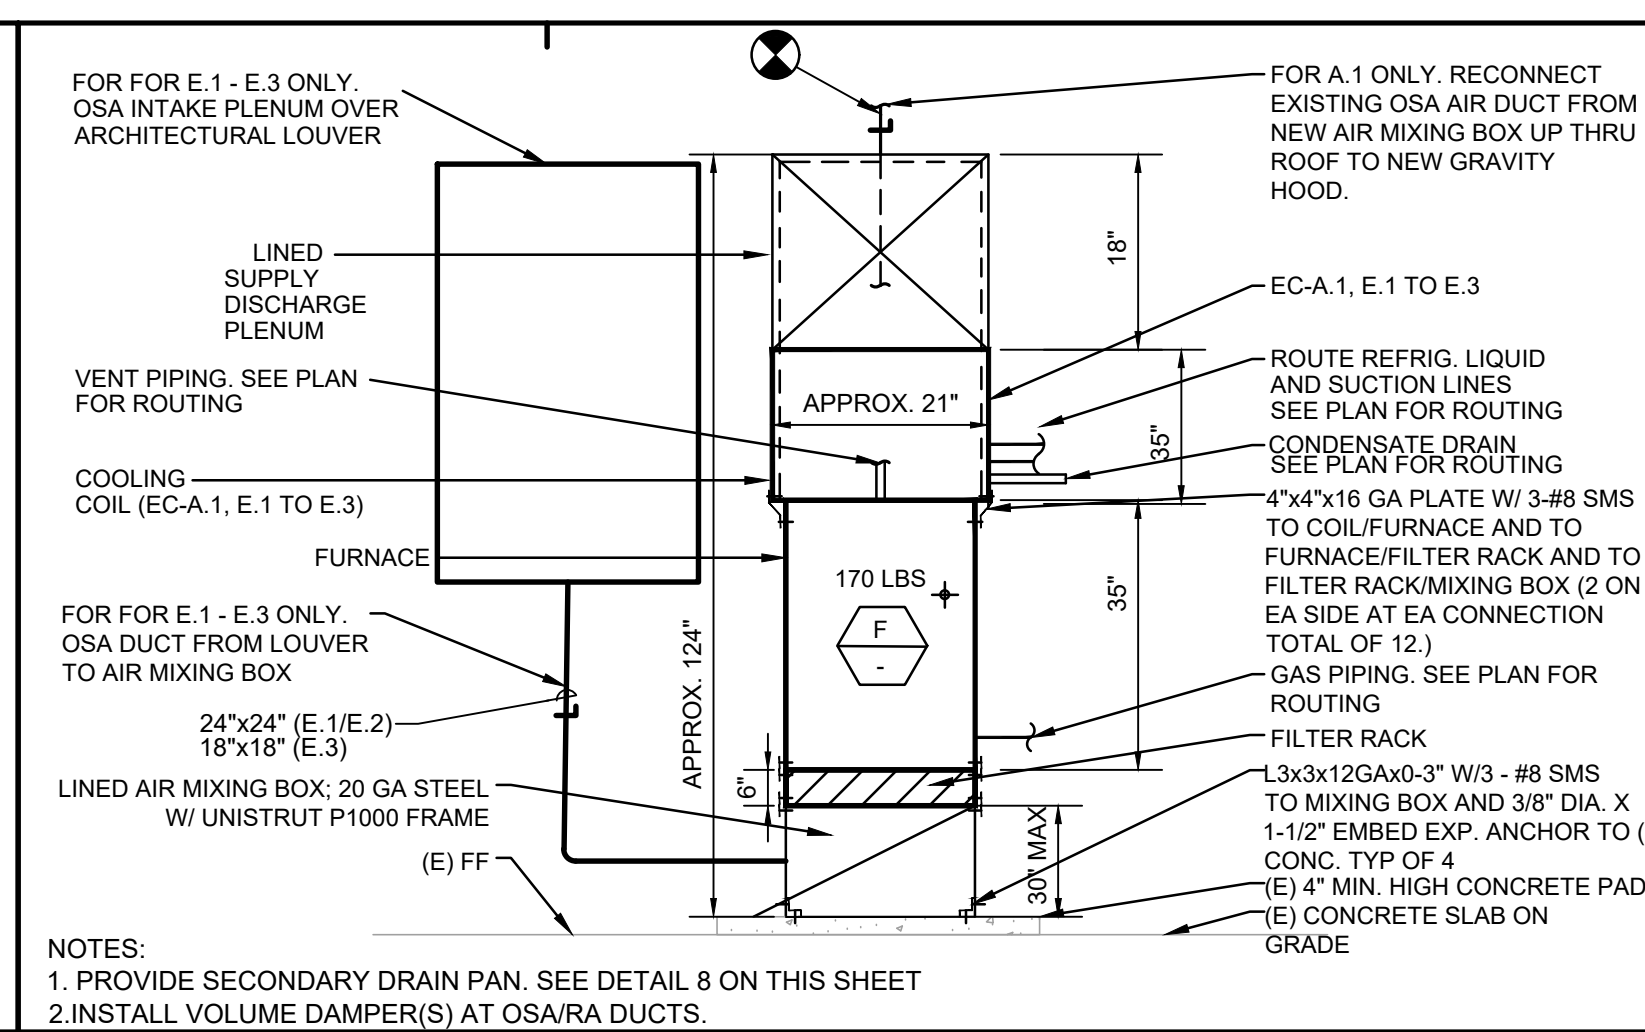


- NOTES:
1. PROVIDE SECONDARY DRAIN PAN. SEE DETAIL 8 ON THIS SHEET
2. INSTALL VOLUME DAMPER(S) AT OSA/RA DUCTS.

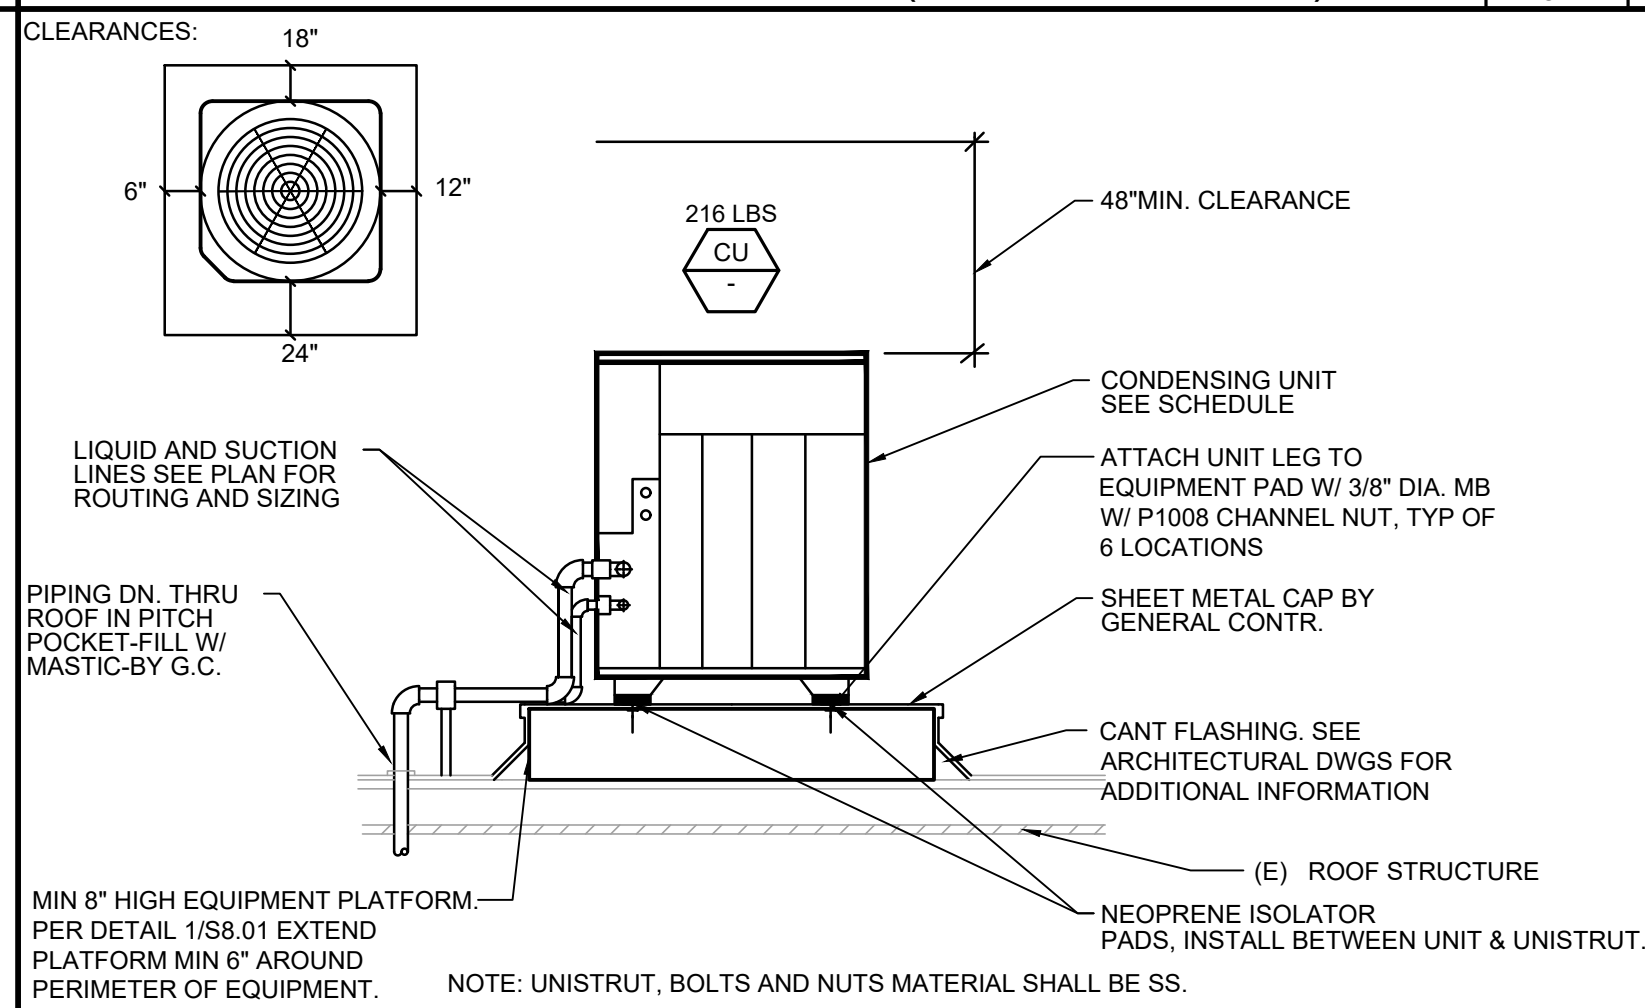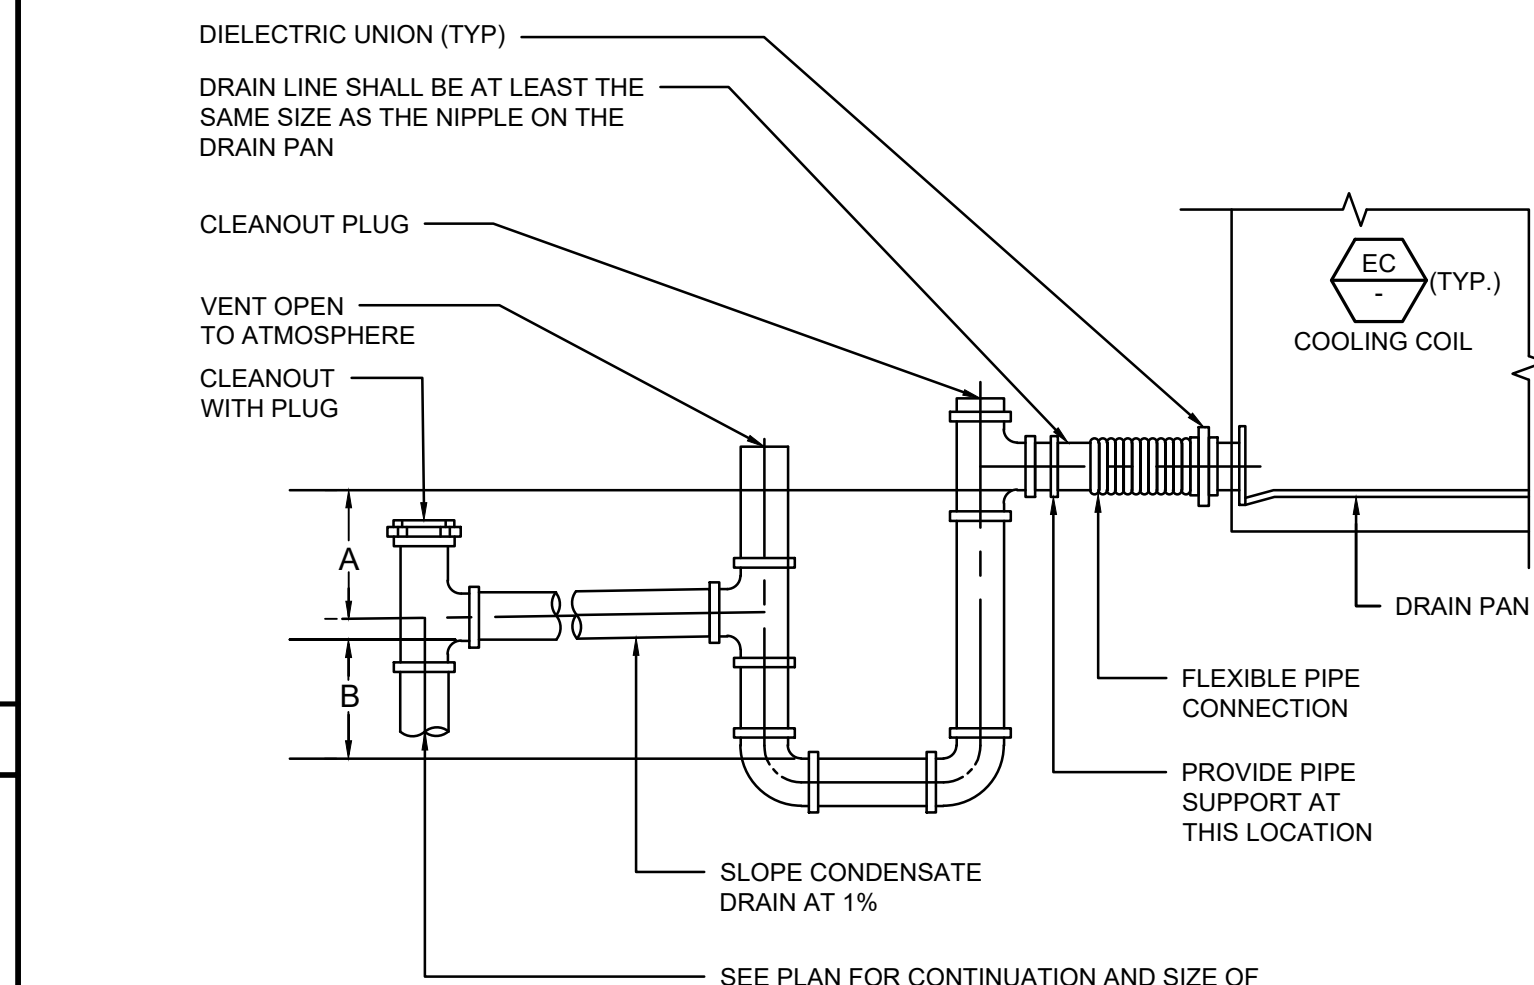

AIR HANDLING UNIT/FAN COIL UNIT	
A	B
SEE NOTE 1	SEE NOTE 2
BLOW THROUGH COIL	
A	B
SEE NOTE 3	SEE NOTE 4

- NOTES:
1. STATIC PRESSURE OF AIR CONDITIONING UNIT PLUS 1".
 2. A/2 MINIMUM.
 3. STATIC PRESSURE OF AIR CONDITIONING UNIT PLUS 1/2".
 4. 1/2" MINIMUM.
 5. INSULATE CONDENSATE PIPING (LOCATED INDOORS)
 6. DO NOT INSTALL TRAPS ON FCU(S) WITH INTEGRAL CONDENSATE PUMPS

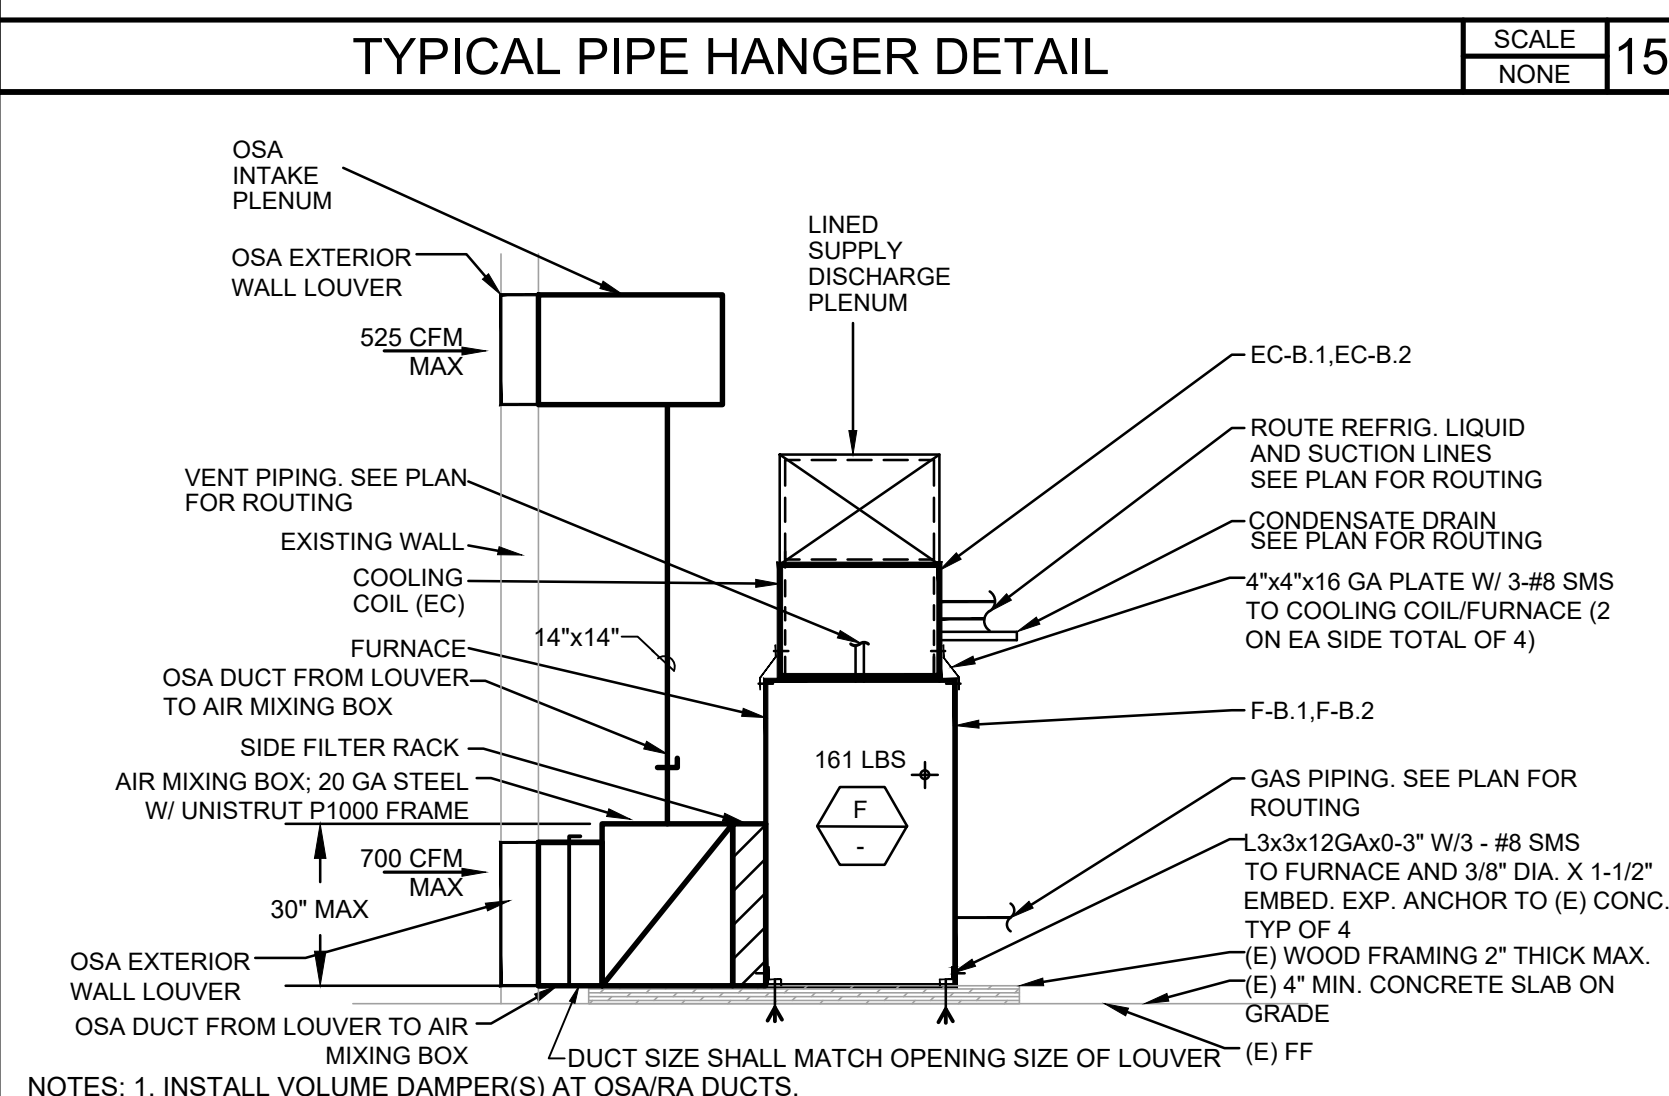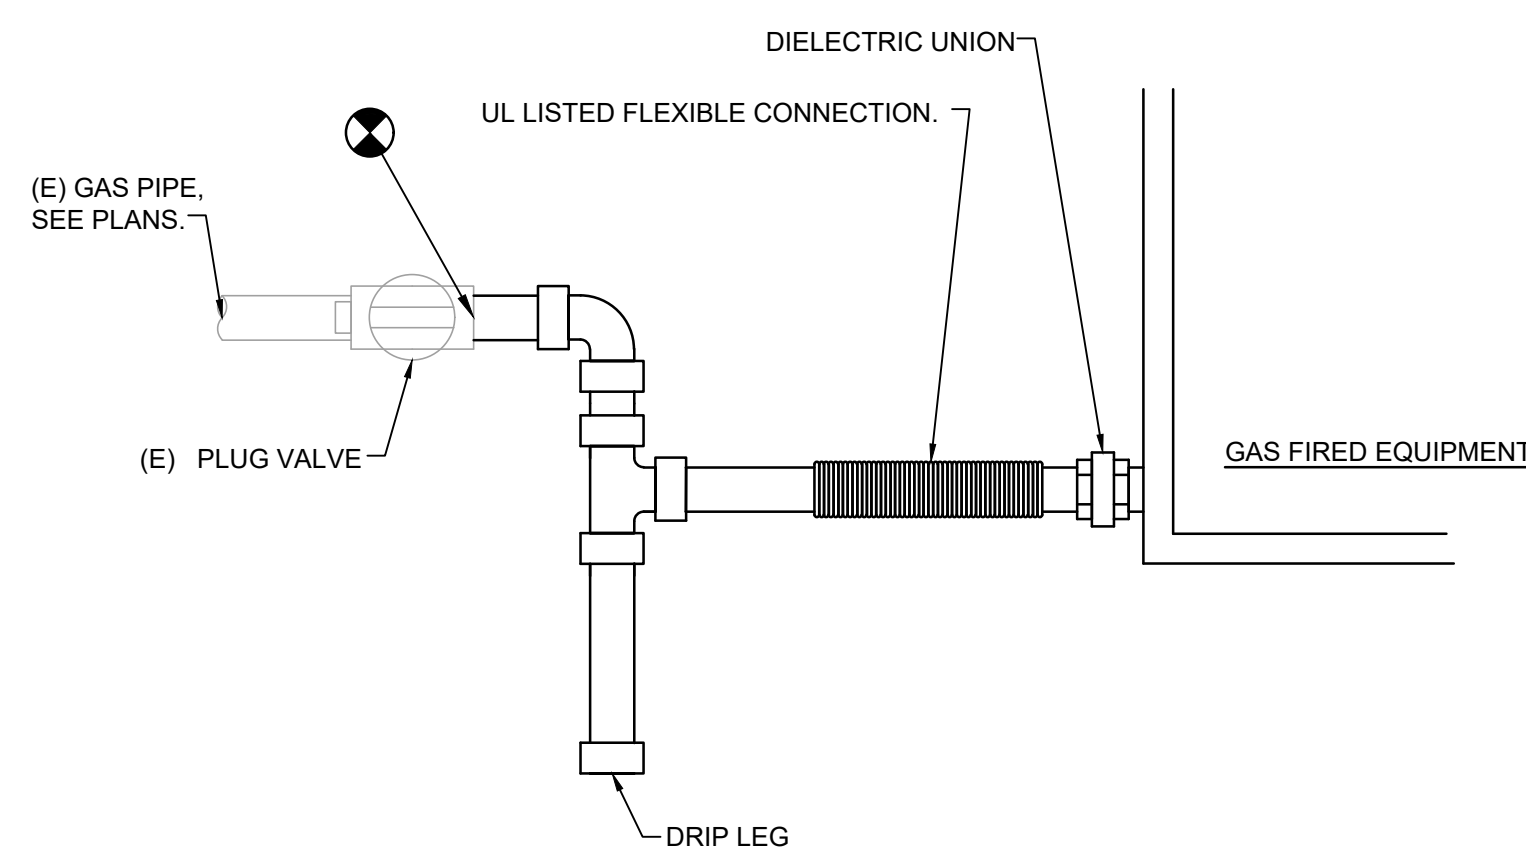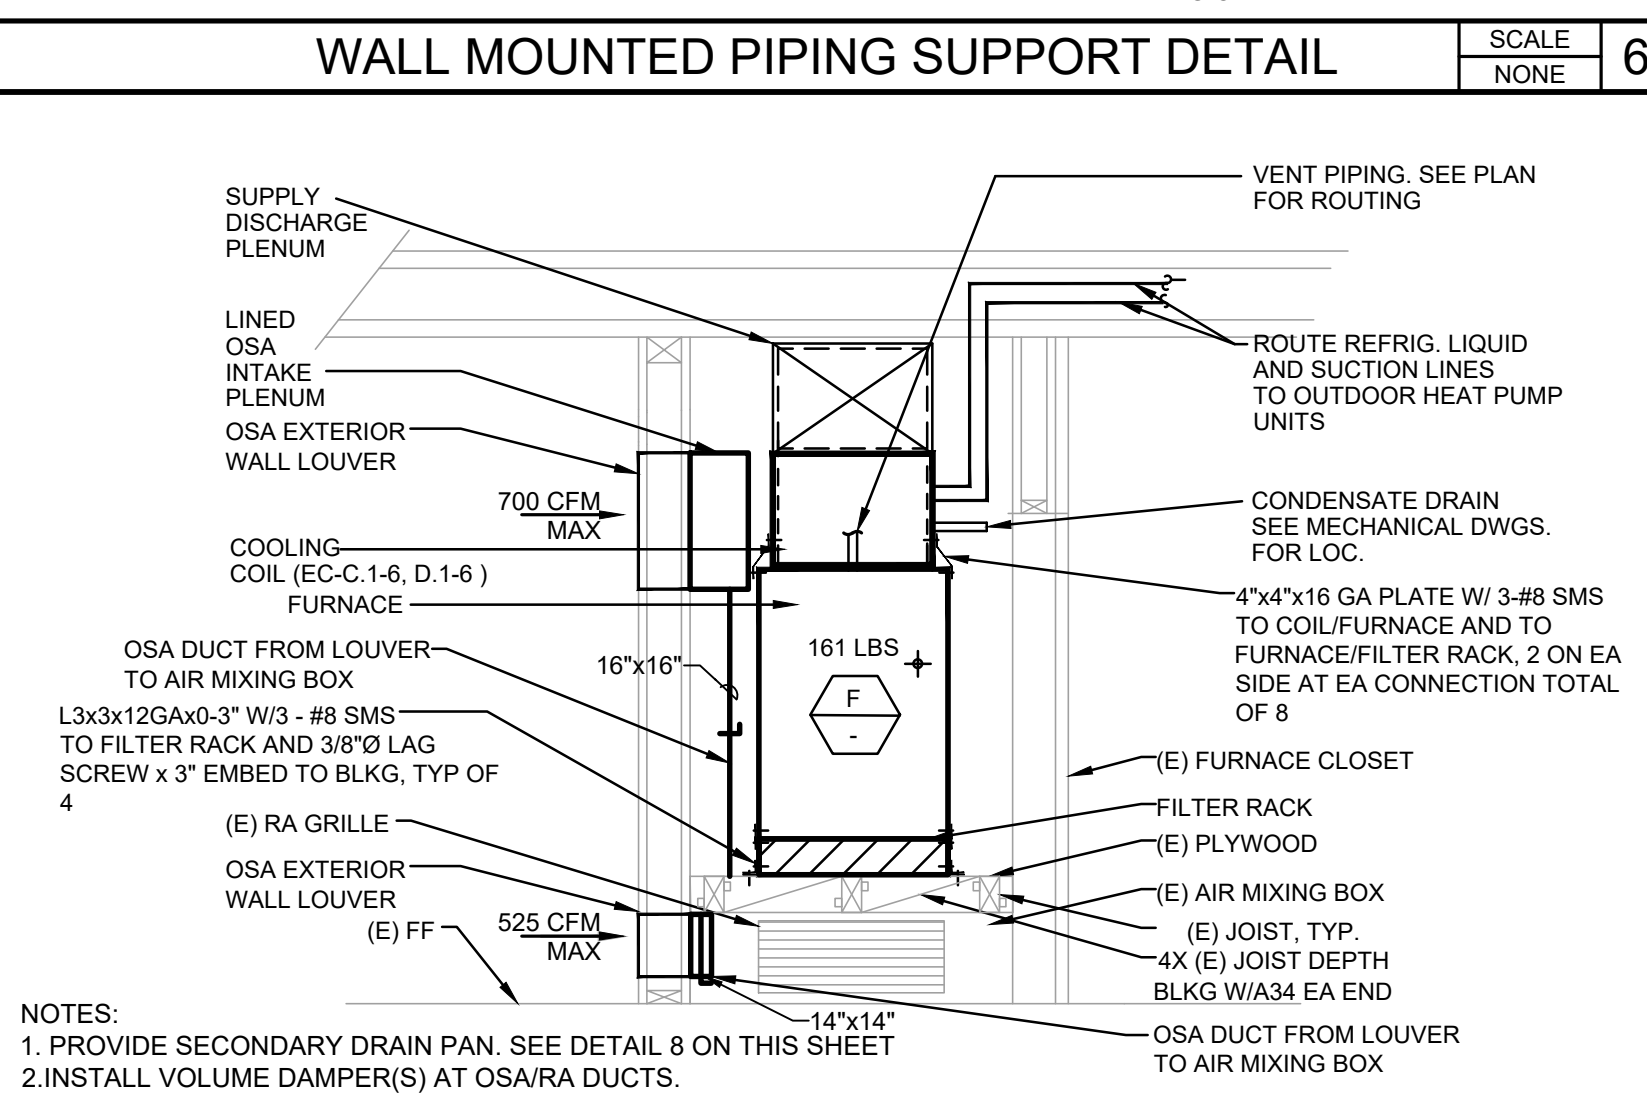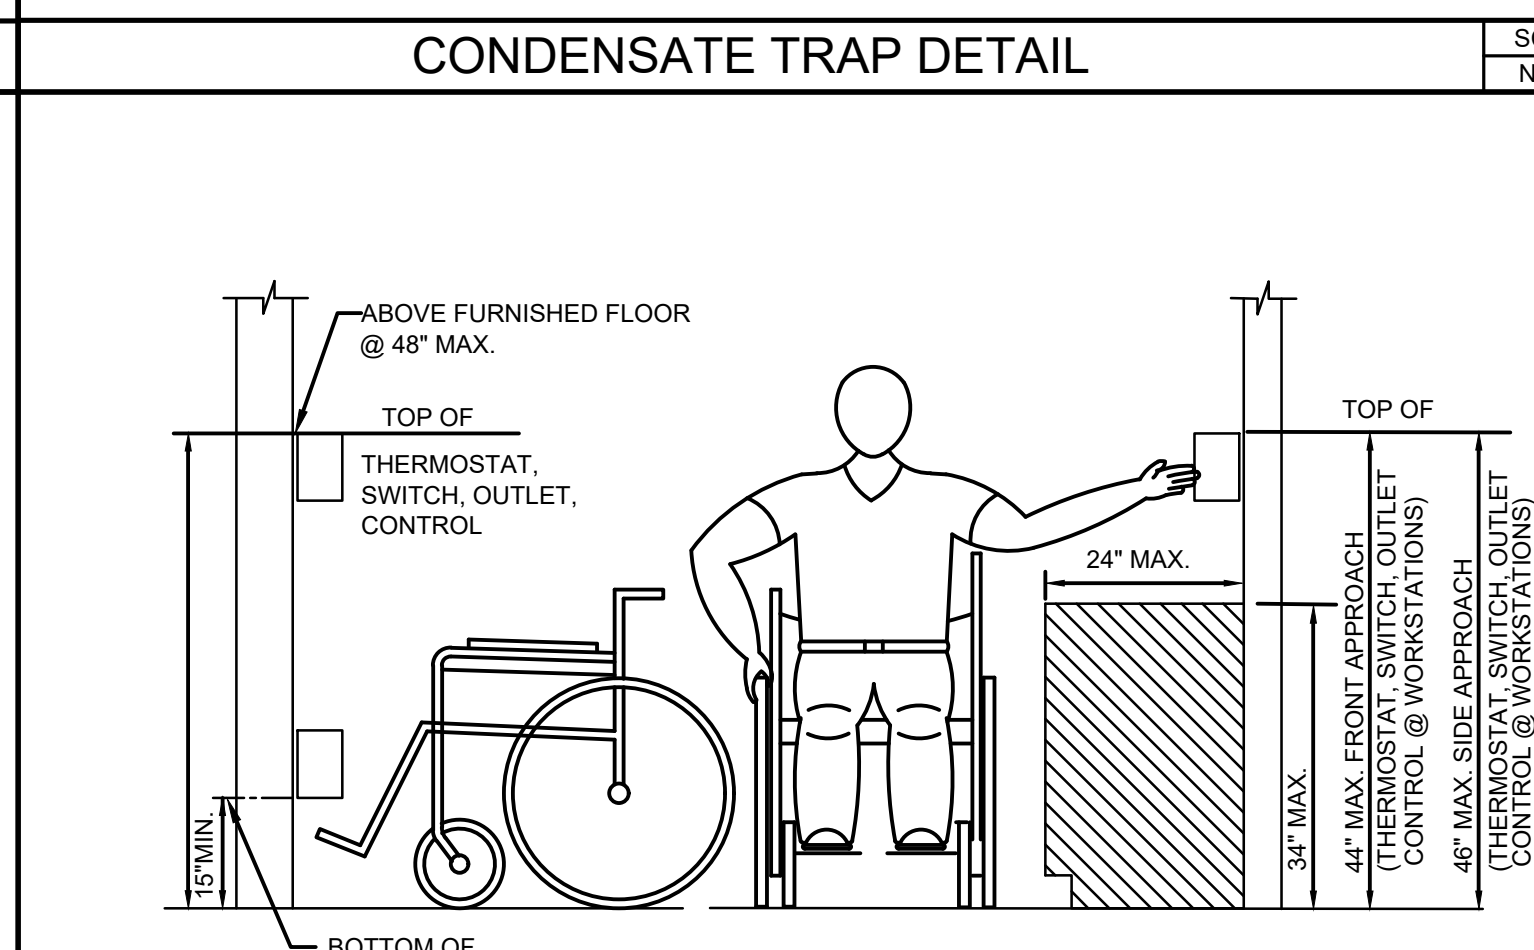

IDENTIFICATION STAMP
DIV. OF THE STATE ARCHITECT
APP: 01-122566 INC:
REVIEWED FOR
SS ☒ FLS ☒ ACS ☐
DATE: 3/10/2026



# Revisions			
Delta	Date	Revisions	By

oed optimum
energy
design

Consulting Engineers
5277 College Avenue
Oakland, CA 94618
Telephone (510) 837-9182



HY HIBSER YAMAUCHI
Architects, Inc.
300 - 27th Street
Oakland, CA 94612
510.444.2222 tel. 510.444.2211 fax

HY Architects Project number:	Project Number
-------------------------------	----------------

Facility
SKYLINE ELEMENTARY SCHOOL
55 CHRISTEN AVE, DALY CITY, CA 94015

Project HVAC REPLACEMENT

Sheet Title

MECHANICAL DETAILS

Client Project Number:	0000.0
------------------------	--------

Scale:	Not to Scale	She
--------	--------------	-----

Drawn By: CC






Checked B

Issue Date:

M3.01

Sheet of

3/26/2023 3:12:50 PM M:\P - PROJECTS\2025002-25-0001 SFUSD SKYLINE ES\02_MECH

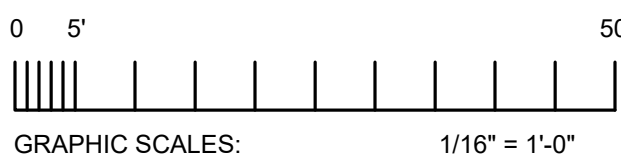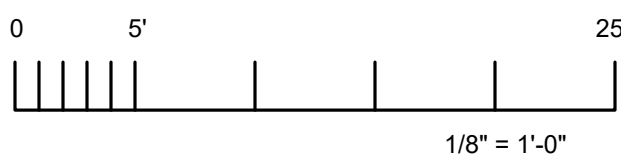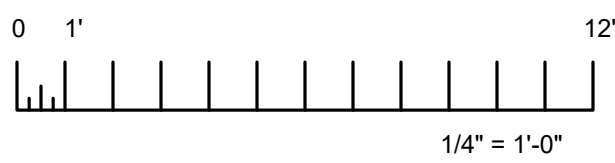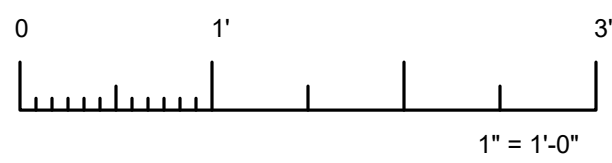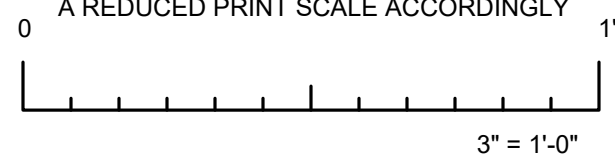


IF THIS SHEET IS NOT 30"x42", IT IS
A REDUCED PRINT SCALE ACCORDINGLY

IDENTIFICATION STAMP
DIV. OF THE STATE ARCHITECT
APP: 01-122566 INC:
REVIEWED FOR
SS ☒ FLS ☒ ACS ☐
DATE: 3/10/2026



#	Revisions	By
Delta	Date	Revisions

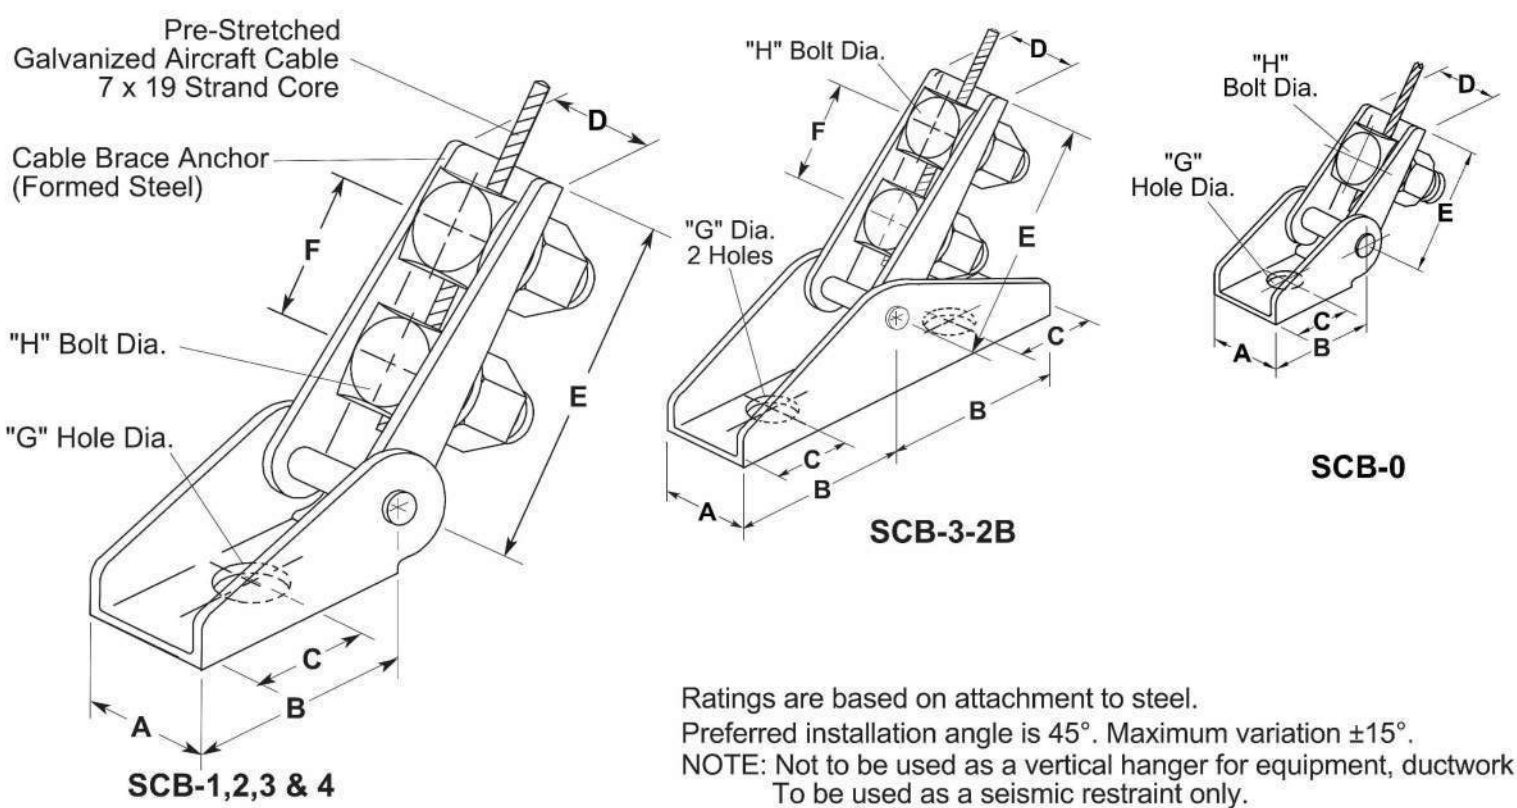

Ratings are based on attachment to steel.
Preferred installation angle is 45°. Maximum variation ±15°.
NOTE: Not to be used as a vertical hanger for equipment, ductwork or piping.
To be used as a seismic restraint only.

SCB-1,2,3 & 4

TYPE SCB DIMENSION (in mm)

Size	A	B	C	D	E	F	G	H
SCB-0	19/16 33	1 1/2 38	3/4 19	15/16 24	1 3/4 44	-	7/16 11	1 1/2 13
SCB-1	19/16 35	2 51	1 25	15/16 24	3 3/8 86	1 1/2 38	9/16 14	1 1/2 13
SCB-2	19/8 41	2 3/4 70	1 3/8 35	1 3/16 30	4 3/8 111	1 3/4 44	1 1/16 17	5/8 16
SCB-3	2 51	3 1/2 89	1 3/4 44	1 7/16 37	4 3/4 121	2 51	1 3/16 21	3/4 19
SCB-3-2B	2 51	4 3/4 121	1 25	1 7/16 37	4 3/4 121	2 51	1 3/16 21	3/4 19
SCB-4	3 1/8 79	5 127	2 1/2 64	1 15/16 49	5 3/4 146	2 1/4 57	1 5/16 33	1 25


TYPE SCB ASSEMBLY RATINGS
AS CONTROLLED BY CABLE BREAKING STRENGTH

Size	Cable Diameter		Max. Ratings			Torque on Bolts		
	in	mm	lbs	kN	kg	ft-lbs	N-m	kg-m
SCB-0	1/16"	1.6	235	1.0	106	30	41	4.2
SCB-0	3/32"	2.4	460	2.1	208	30	41	4.2
SCB-0	3/32	2.4	500	2.2	227	30	41	4.2
SCB-1	1/8	3	975	4.3	442	25	34	3.5
SCB-2	3/16	5	2050	9.1	930	45	61	6.2
SCB-3 & -3-2B	1/4	6	3150	14.0	1429	55	75	7.6
SCB-4	3/8	10	6875	30.5	3119	200	271	27.6

* 7 x 7 STRAND CORE

SCB SEISMIC CABLE BRACE

SCALE	3
NONE	

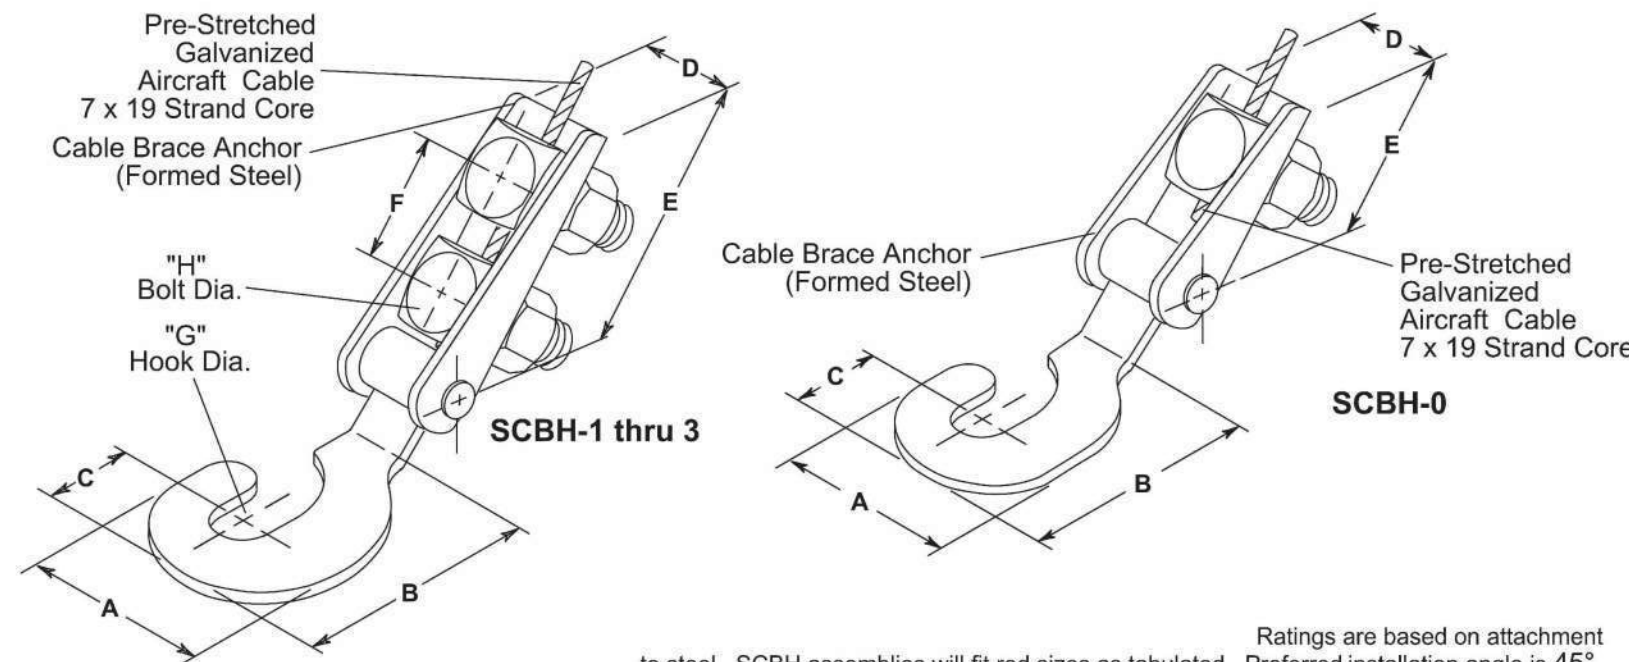

Ratings are based on attachment to steel. SCBH assemblies will fit rod sizes as tabulated. Preferred installation angle is 45°. Maximum variation is ± 15°.

TYPE SCBH DIMENSIONS (inches mm)

Size	For use with Rod Sizes	A	B	C	D	E	F	G	H									
SCBH-0	3/8	10	1 3/8	35	2 1/16	52	1 1/16	17	15/16	24	1 3/4	44	--	3/8	10	1/2	13	
SCBH-1	1/2, 5/8	13, 16	1 7/8	48	2 3/8	60	1	25	1	25	3 3/8	86	1 1/2	38	5/8	16	1/2	13
SCBH-2	3/4, 7/8	19, 22	2 7/8	73	3 3/4	95	1 3/8	35	1 3/16	30	4 3/8	111	1 3/4	44	7/8	22	5/8	16
SCBH-3	1, 1 1/8	25, 29	3 1/2	89	4 3/4	121	1 3/4	44	1 7/16	37	4 3/4	121	2	51	1 1/8	29	3/4	19


TYPE SCBH ASSEMBLY RATINGS
AS CONTROLLED BY CABLE BREAKING STRENGTH

AS CONTROLLED BY CABLE BREAKING STRENGTH								
Size	Cable Diameter		Max. Ratings			Torque on Bolts		
	in	mm	lbs	kN	kg	ft-lbs	N-m	kg-m
SCBH-0	1/16"	1.6	235	1.0	107	30	41	4.2
SCBH-0	3/32"	2.4	460	2.1	209	30	41	4.2
SCBH-0	3/32	2.4	500	2.2	227	30	41	4.2
SCBH-1	1/8	3	975	4.3	442	25	34	3.5
SCBH-2	3/16	5	2050	9.1	930	45	61	6.2
SCBH-3	1/4	6	3150	14.0	1429	55	75	7.6

* 7 x 7 STRAND CORE

SCBH SEISMIC BRACE


SCALE	2
NONE	

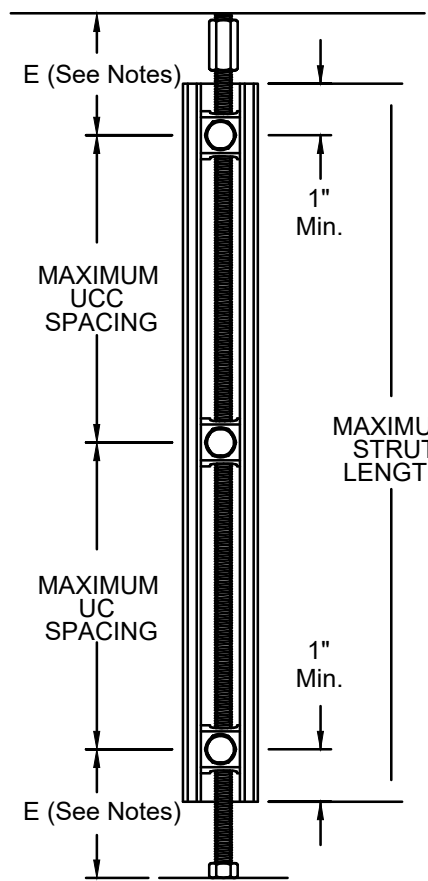

NOTE 1:
E = 3" MAXIMUM FOR 1/4" TO 1/2" RODS, AND E = 6" MAXIMUM FOR 5/8" TO 1-1/4" DIAMETER RODS. A MINIMUM OF (2) UCC SEISMIC ROD CLAMPS PER STIFFENER ANGLE ARE REQUIRED.


ROD STIFFENER FOR THE UCC

SCALE	4
NONE	

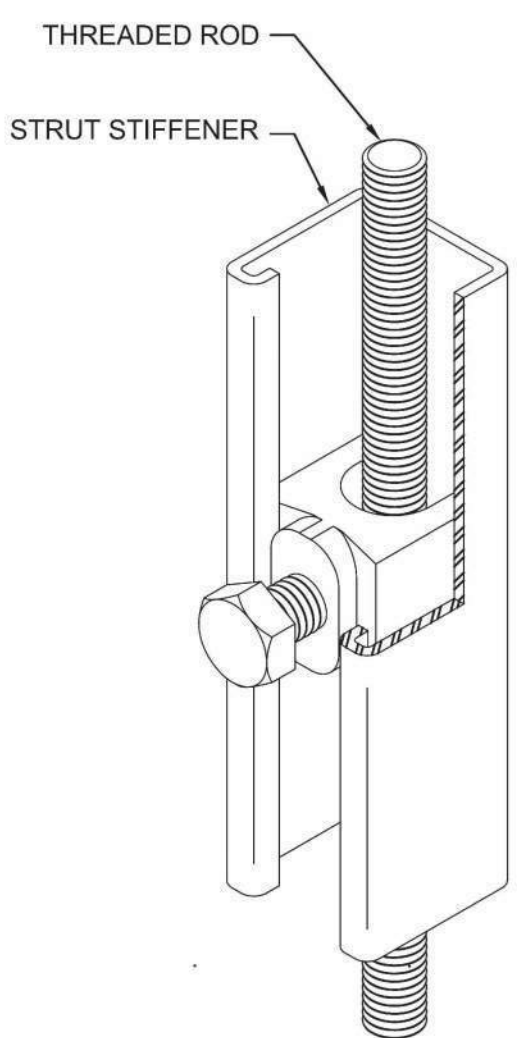

TYPE UCC WITH STEEL STRUT ASSEMBLY RATINGS

Rod Size in (mm)	Maximum Compressive Force lbs (kN)	Strut Stiffener		Maximum UCC Spacing in (mm)
		Minimum Size in (mm)	Max Length in (mm)	
3/8 (10)	425 (1.9)	1 5/8 x 1 5/8 x 12 Gage (41 x 41 x 2.5)	96 (2438)	22 (559)
1/2 (13)	1275 (5.6)	1 5/8 x 1 5/8 x 12 Gage (41 x 41 x 2.5)	96 (2438)	31 (787)
	1200 (5.3)	1 5/8 x 1 5/8 x 12 Gage (41 x 41 x 2.5)	120 (3048)	31 (787)
5/8 (16)	1475 (6.5)	1 5/8 x 1 5/8 x 12 Gage (41 x 41 x 2.5)	96 (2438)	39 (991)
	1325 (5.9)	1 5/8 x 1 5/8 x 12 Gage (41 x 41 x 2.5)	120 (3048)	39 (991)
3/4 (19)	2500 (11.1)	1 5/8 x 1 5/8 x 12 Gage (41 x 41 x 2.5)	144 (3658)	48 (1212)

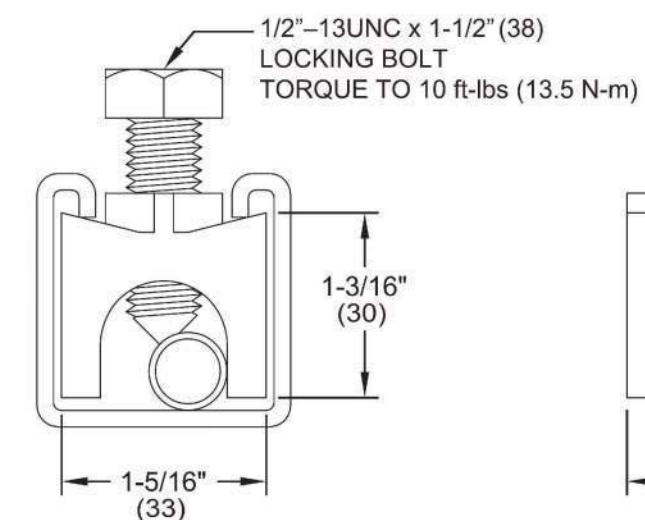

UCC CLAMP

SCALE	1
NONE	

This document is the property of the Owner and is not to be used without their written permission



HY HIBSER YAMAUCHI Architects, Inc.

300 - 27th Street
Oakland, CA 94612
510.446.2222 tel | 510.446.2211 fax

HY Architects Project number: Project Number

Facility
SKYLINE ELEMENTARY SCHOOL
55 CHRISTEN AVE, DALY CITY, CA 94015

Project

HVAC REPLACEMENT

Sheet Title

MECHANICAL DETAILS

Client Project Number: 0000.0

Scale: Not to Scale

Drawn By: CC

Checked By: AK

Issue Date:

Revit Version: 2023

Sheet

of

M3.02

3/20/2025 3:12:50 PM M:\P - PROJECTS\20250502-25-0001 SFUSD SKYLINE ES\02_MECH



IF THIS SHEET IS NOT 30"x42", IT IS
A REDUCED PRINT SCALE ACCORDINGLY


IDENTIFICATION STAMP
DIV. OF THE STATE ARCHITECT
APP: 01-122566 INC:
REVIEWED FOR
SS ☒ FLS ☒ ACS ☐
DATE: 3/10/2026



#	Revisions
Delta	Date Revisions By

- NOTES:
1. PROVIDE DEMAND CONTROL VENTILATION ONLY WITH INTEGRAL CO2 SENSOR FOR BLDGS. B, C, D NEW HVAC EQUIPMENT INCLUDING BLDG. E, F/EC/UCU-E.1 & E.2.
 2. EXISTING SMOKE DETECTOR FOR F/EC/UCU-E.1 & E.2 SHALL BE RE-USED. REMOVE AND RE-STALL EXISTING DUCT MOUNTED SMOKE DETECTOR AS REQUIRED.
 3. REMOVE EXISTING DDC CONTROLLERS FROM ASSOCIATED EXISTING FURNACES AND SPLIT SYSTEMS BEING REMOVED. CONTRACTOR SHALL FIELD VERIFY THEIR LOCATIONS. INSTALL UNITARY CONTROLLERS FOR NEW WORK.
 4. BLDG. E THERMOSTAT FOR F/EC/UCU-E.1 IS SLAVE TO F/EC/UCU-E.2.
 5. PROVIDE SS CONSTRUCTED COUNTERBALANCE BACKDRAFT DAMPERS FOR ALL BLDGS. RELIEF AIR HOODS. FURNISHED AND INSTALLED BY MECHANICAL CONTRACTOR.
 6. REPLACE EXISTING DDC CONTROLLERS WITH NEW INCLUDING ACTUATORS AND OSA/RA DAMPERS FOR ALL BUILDINGS. INSTALL SS CONSTRUCTED DAMPERS INCLUDING LINKAGES BY MECHANICAL. 24V MOTORIZED DAMPER ACTUATORS BY CONTROL CONTRACTOR.
 7. DISCONNECT AND SAFE-OFF EXISTING CONTROL WIRING. RE-CONNECT AT NEW WORK INSTALLATION.
 8. RETAIN EXISTING POWER AND RECONNECT AT NEW WORK INSTALLATION.
 9. PROVIDE 100% ENTHALPY TYPE ECONOMIZER. THE OSA DAMPER SHALL CLOSE, IF OSA ENTHALPY IS GREATER THAN RETURN AIR.

- FURNACE/CONDENSING UNIT SPLIT SYSTEM WITH ECONOMIZER, DEMAND CONTROL VENTILATION & ZONE OCCUPANCY MONITORING
1. SYSTEM OVERVIEW
 - a. EACH FRN/CU UNIT WILL BE DIRECTLY CONTROLLED BY A DEDICATED EMS (ENERGY MANAGEMENT SYSTEM) UNITARY CONTROLLER.
 - b. EMS UNITARY CONTROLLER WILL BE CONNECTED TO A WALL MOUNTED ELECTRONIC ZONE TEMPERATURE SENSOR.
 - c. ELECTRONIC ZONE TEMPERATURE SENSOR SHALL HAVE A TOUCH SCREEN LCD INTERFACE WHICH INCLUDES: 1) DIGITAL PUSHBUTTONS FOR WARMER/COOLER SETPOINT CONTROL; 2) VISUAL DISPLAY OF ROOM TEMPERATURE, ROOM CO2 (SEE NOTE 1) AND AMBIENT OSA TEMPERATURE; AND 3) DIGITAL PUSHBUTTON AFTER-HOURS OVERRIDE TIMER CONTROL. WITH USER ADJUSTABLE DURATION. THE AFTER-HOURS OVERRIDE DURATION SHALL HAVE THE ABILITY TO BE LIMITED FROM THE FRONT-END.
 2. UNIT FAN OPERATION
 - a. WHEN THE ZONE IS IN OCCUPIED MODE OR IN AFTER HOURS MODE, THE FAN SHALL RUN CONTINUOUSLY, UNLESS VACANT MODE HAS BEEN TRIGGERED.
 - b. DURING THE UNOCCUPIED MODE AS DETERMINED BY EMS TIME SCHEDULE, THE UNIT FAN CYCLES WITH DEMAND AND THE TEMPERATURE IS CONTROLLED BY THE UNOCCUPIED SPACE TEMPERATURE HEATING AND COOLING SETPOINTS.
 3. MINIMUM OUTDOOR AIR VENTILATION
 - a. DURING OCCUPIED MODE OR AFTERHOURS MODE, THE ECONOMIZER DAMPER SHALL BE COMMANDED BY THE EMS UNITARY CONTROLLER TO MAINTAIN A POSITION WHICH SATISFIES THE MINIMUM OUTDOOR AIR VENTILATION REQUIREMENTS FOR THE ZONE. DAMPER POSITION(S) DETERMINED BY AIR BALANCING CONTRACTOR.
 5. DEMAND CONTROL VENTILATION, SEE NOTE 1
 - a. EMS UNITARY CONTROLLER WILL BE CONNECTED TO A WALL MOUNTED CO2 SENSOR TO MONITOR ZONE CO2 CONCENTRATION.
 - b. DURING OCCUPIED MODE OR AFTERHOURS MODE, THE EMS UNITARY CONTROLLER SHALL RESET THE OUTSIDE AIR DAMPER MINIMUM POSITION TO MAINTAIN THE CO2 CONCENTRATION BELOW 1,000 PPM.
 6. VACANT MODE CONTROL
 - a. WHEN THE ZONE HAS BEEN SCHEDULED FOR OCCUPANCY FOR AT LEAST ONE HOUR AND THE OCCUPANCY SENSOR HAS CONFIRMED THAT ZONE HAS BEEN VACANT FOR 5 MINUTES (ADJUSTABLE. MAXIMUM 30 MINUTES), ZONE SHALL BE PLACED INTO VACANT MODE.
 - b. RESET COOLING AND HEATING SETPOINTS UP AND DOWN BY 2°F (ADJUSTABLE) OR MORE.
 - c. VENTILATION AIR IN A VACANT ZONE SHALL BE REDUCED TO ZERO WHEN PERMITTED TO DO SO ACCORDING TO 2022 CALIFORNIA TITLE 24 TABLE 120.1A (ALL OCCUPANCY CATEGORIES WITH NOTE 1" DESIGNATION). THE UNIT FAN SHALL BE SHUT OFF AND THE ECONOMIZER SHALL BE CLOSED TO THE OUTSIDE AIR. FOR ALL OTHER ZONES, THE ECONOMIZER SHALL BE SET TO MINIMUM OUTDOOR AIR POSITION AND THE UNIT FAN SHALL OPERATE TO PROVIDE MINIMUM VENTILATION DURING VACANT MODE.
 - d. UPON DETECTION OF OCCUPANCY, VACANT MODE SHALL BE CLEARED.
 7. ZONE PRE-OCCUPANCY PURGE
 - a. THE EMS SHALL SCHEDULE THE ZONE TO BE IN OCCUPIED MODE ONE HOUR PRIOR TO THE ACTUAL TIME OF ANTICIPATED OCCUPANCY.
 8. HEATING OPERATION
 - a. THE CONTROLLER COMPARES THE HEATING SETPOINT WITH THE SPACE TEMPERATURE AND DETERMINES A NEED-HEATING CONTROL SIGNAL TO STAGE A GAS REGULATING VALVE ON THE UNIT.
 - b. ECONOMIZER TO BE COMMANDED TO MIN CFM SETPOINT AND MECHANICAL COOLING TO BE LOCKED OUT DURING HEATING MODE.
 9. COOLING OPERATION
 - a. THE CONTROLLER COMPARES THE COOLING SETPOINT WITH THE SPACE TEMPERATURE AND DETERMINES A NEED-COOLING SIGNAL.
 - b. THE FIRST STAGE OF COOLING WILL ENABLE THE ECONOMIZER TO PROVIDE FREE COOLING FOR AS LONG AS POSSIBLE.
 - c. THE SECOND STAGE OF COOLING WILL ENABLE THE COMPRESSOR(S) TO MAINTAIN THE ROOM SET POINT.
 10. FAULT DETECTION DIAGNOSTICS
 - a. THE EMS DDC CONTROLLER SHALL MONITOR THE FOLLOWING ECONOMIZER ACTUATOR FAULT DETECTION DIAGNOSTIC CONDITIONS AND BROADCAST RESULTS VIA EMS NETWORK:
 - TEMPERATURE SENSOR FAILURE/FAULT
 - ECONOMIZER NOT ECONOMIZING WHEN ENABLED
 - ECONOMIZER ECONOMIZING WHEN DISABLED
 - ECONOMIZER DAMPER MODULATION FAILURE
 - EXCESS OUTDOOR AIR
 11. MONITORING - THE FOLLOWING CONDITIONS SHALL BE MONITORED AND DISPLAYED AT EXISTING EMS OPERATOR WORKSTATION/GRAPHICAL USER INTERFACE:
 - a. SUPPLY AIR TEMPERATURE.
 - b. ROOM TEMPERATURE.
 - c. ROOM CO2 CONCENTRATION.
 - d. CURRENT MODE (HEATING/COOLING/FAN).
 - e. SUPPLY AIR TEMPERATURE ATTAINED LAST TIME UNIT WAS IN HEATING.
 - f. SUPPLY AIR TEMPERATURE ATTAINED LAST TIME UNIT WAS IN COOLING.
 - g. CURRENT COMMAND STATUS OF FAN, ECONOMIZER, COMPRESSOR AND GAS VALVE.
 - h. RUN TIME METERS ON FAN, COMPRESSOR, AND HEAT.
 - i. FAN STATUS THRU CURRENT SWITCH.
 - j. ECONOMIZER ACTUATOR FEEDBACK STATUS.

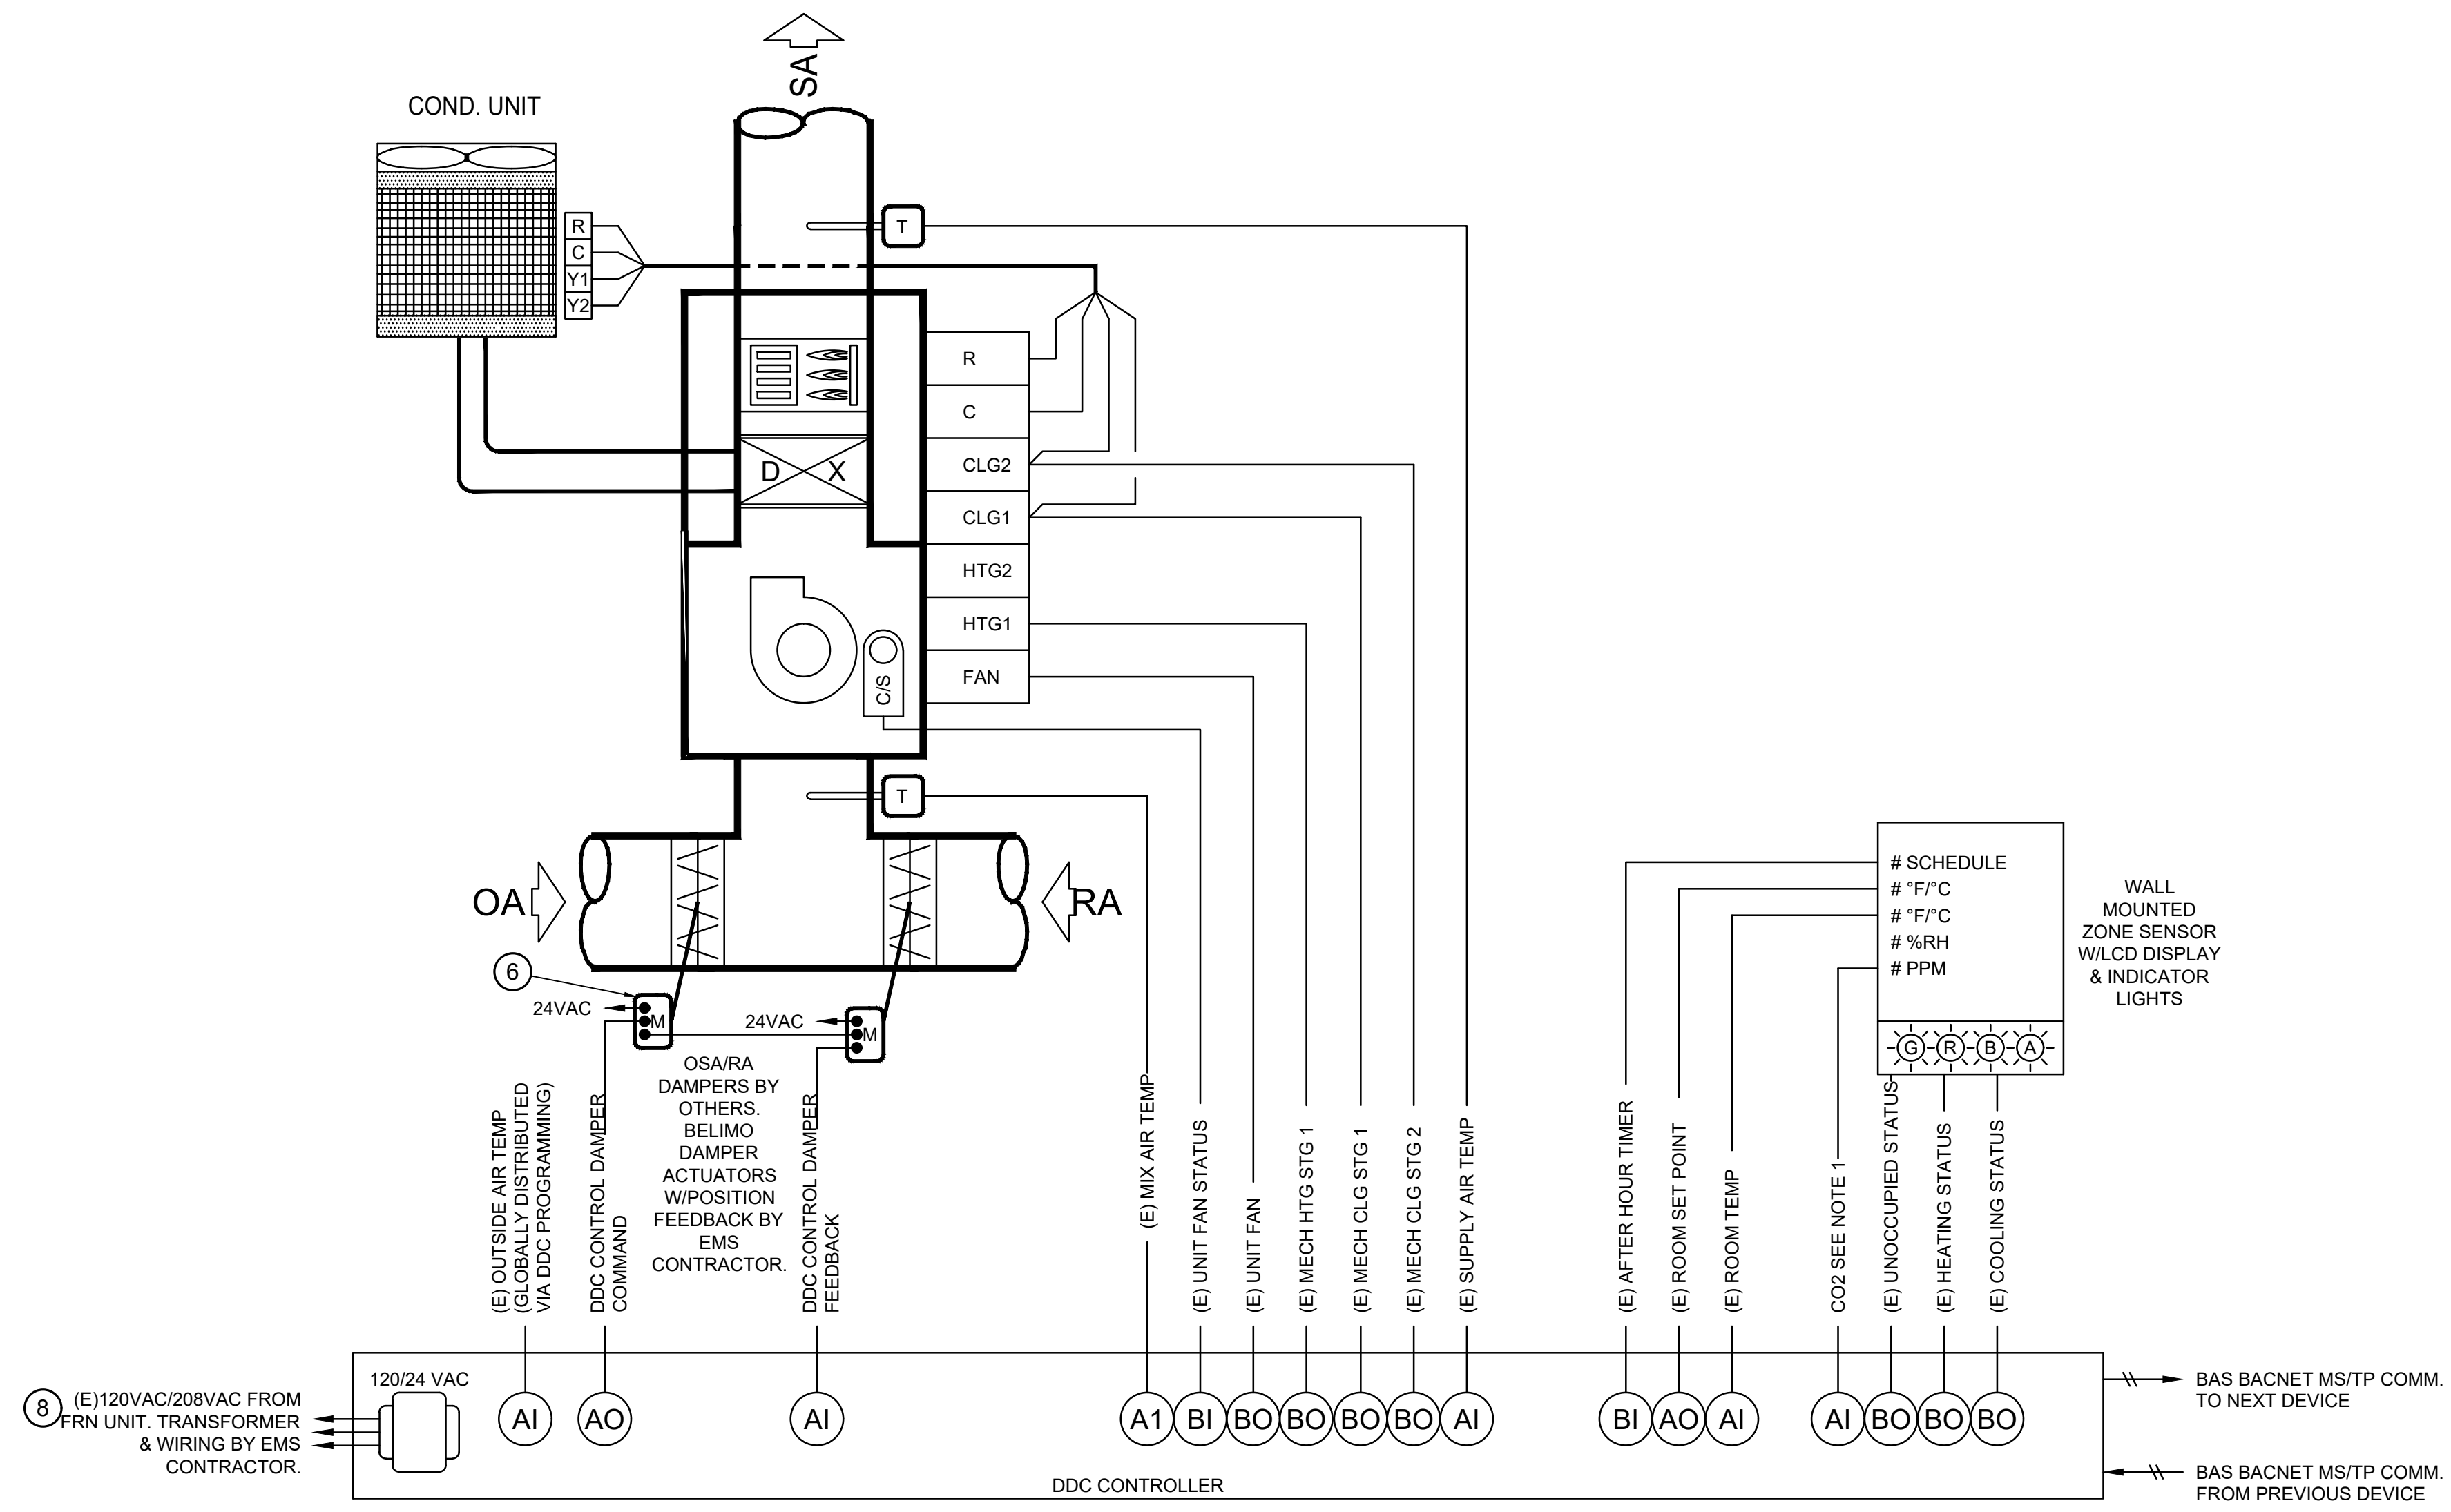

FRN/CU SPLIT SYSTEM w/ECONOMIZER,DEMAND CONTROL VENTILATION, ZONE OCCUPANCY F/EC/UCU-A.1, B.1-B.2, C.1 TO C.6, D.1 TO D.6, & E.1 TO E.3

1/8" = 1'-0"

1

Client Project Number:	0000.0
Scale:	Not to Scale
Drawn By:	CC
Checked By:	AK
Issue Date:	
Revit Version:	2023

Sheet

of

M4.01

MECHANICAL EMS CONTROL
DIAGRAM

HVAC REPLACEMENT







SKYLINE ELEMENTARY SCHOOL
55 CHRISTEN AVE, DALY CITY, CA 94015

HIBSER YAMAUCHI
Architects, Inc.
300 - 27th Street
Oakland, CA 94612
510.446.2222 tel | 510.446.2211 fax




oed optimum
energy design
Consulting Engineers
5277 College Avenue
Oakland, CA 94618
Telephone (510) 837-9182

3/20/2025 3:12:50 PM M:\P - PROJECTS\20250925-0001 SFUSD SKYLINE ES\02_MECH

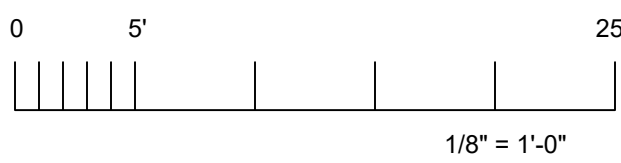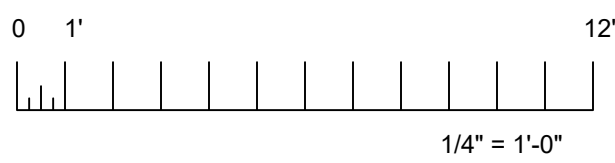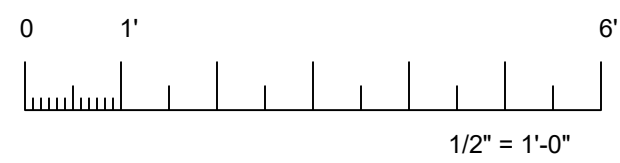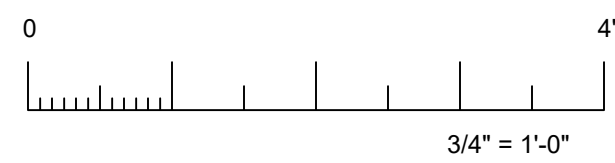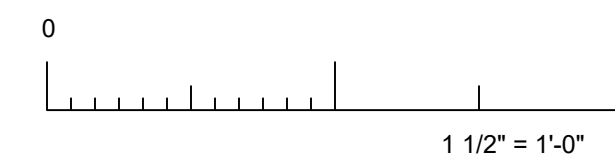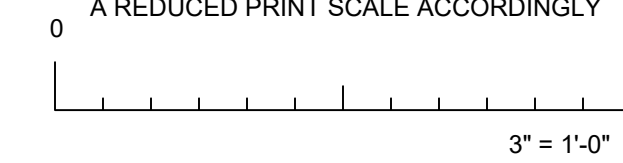

IF THIS SHEET IS NOT 30"x42", IT IS
A REDUCED PRINT SCALE ACCORDINGLY

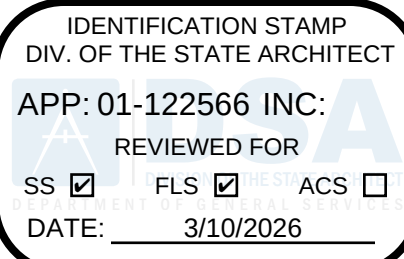

#	Revisions
Delta	Date Revisions By



Consulting Engineers
5277 College Avenue
Oakland, CA 94618
Telephone (510) 837-9182



HY Architects Project number: Project Number

SKYLINE ELEMENTARY SCHOOL
55 CHRISTEN AVE, DALY CITY, CA 94015

Project
HVAC REPLACEMENT

Sheet Title

MECHANICAL TITLE 24 FORMS

Client Project Number: 0000.0

Scale: Not to Scale
Drawn By: CC
Checked By: AK
Issue Date:
Revit Version: 2023
Sheet of
M5.01

CERTIFICATE OF COMPLIANCE - NONRESIDENTIAL PERFORMANCE COMPLIANCE METHODNRCC-PRF-E

Nonresidential Performance Compliance Method(Page 1 of 17)

Project Name:Skyline Elementary SchoolDate Prepared:2025-09-10

A. General Information

1	Project Name	Skyline Elementary School			
2	Run Title	Title 24 Analysis			
3	Project Location	55 CHRISTEN AVE,			
4	City	DALY CITY	5	Standards Version	Compliance 2022
6	Zip code	94015	7	Compliance Software (version)	EnergyPro 9.4
8	Climate Zone	3	9	Building Orientation (deg)	270
10	Building Type(s)	• Nonresidential			
12	Project Scope	• Existing alteration			
14	Total Conditioned Floor Area in Scope (ft²)	18349	15	Total # of hotel/motel rooms	0
16	Total Unconditioned Floor Area (ft²)	0	17	Fuel Type	Natural gas
18	Nonresidential Conditioned Floor Area	18349	19	Total # of Stories (Habitable Above Grade)	1
20	Residential Conditioned Floor Area	0			

CA Building Energy Efficiency Standards - 2022 Nonresidential ComplianceReport Version: 2022.0.000Schema Version: rev 20220601Report Generated: 2025-09-10 14:33:35Compliance ID: EnergyPro-4917-0925-0243

CERTIFICATE OF COMPLIANCE - NONRESIDENTIAL PERFORMANCE COMPLIANCE METHODNRCC-PRF-E

Nonresidential Performance Compliance Method(Page 4 of 17)

C2. TDV ENERGY COMPLIANCE RESULTS FOR PERFORMANCE COMPONENTS (Annual TDV Energy Use, kBtu/ft² · yr)

COMPLIES¹

Energy Component	Standard Design (TDV)	Proposed Design (TDV)	Compliance Margin (TDV) ¹
Space Heating	18.73	7.63	11.1
Space Cooling	30.06	19	11.06
Indoor Fans	109.76	98.69	11.07
Heat Rejection	0	0	0
Pumps & Misc.	0	0	0
Domestic Hot Water	24.29	24.29	0
Indoor Lighting	33.92	33.92	0
Flexibility	---	---	---
EFFICIENCY COMPLIANCE TOTAL	216.76	183.53	33.23 (15.3%)
Photovoltaics	---	---	---
Batteries	---	---	---
TOTAL COMPLIANCE	216.76	183.53	33.23 (15.3%)

¹ Notes: This number in parenthesis following the Compliance Margin in column 4, represents the Percent Better than Standard.

CA Building Energy Efficiency Standards - 2022 Nonresidential ComplianceReport Version: 2022.0.000Schema Version: rev 20220601Report Generated: 2025-09-10 14:33:35Compliance ID: EnergyPro-4917-0925-0243

CERTIFICATE OF COMPLIANCE - NONRESIDENTIAL PERFORMANCE COMPLIANCE METHODNRCC-PRF-E

Nonresidential Performance Compliance Method(Page 7 of 17)

C8. ENERGY USE INTENSITY (EUI)

	Standard Design (kBtu/ft² / yr)	Proposed Design (kBtu/ft² / yr)	Margin (kBtu/ft² / yr)	Margin Percentage
GROSS EUI ¹	39.17	32.56	6.61	16.88
NET EUI ¹	39.17	32.56	6.61	16.88

¹ Notes: Gross EUI is Energy Use Total (not including PV)/Total Building Area. Net EUI is Energy Use Total (including PV)/Total Building Area.

D1. EXCEPTIONAL CONDITIONS

• The building does not include service water heating. Verify that service water heating is not required and is not included in the design.

H1. DRY SYSTEM EQUIPMENT (FURNACES, AIR HANDLING UNITS, HEAT PUMPS, VRF, ECONOMIZERS ETC.)

01	02	03	04	05	06	07	08	09	10	11	12
Equipment Name	Equipment Type	Qty	Total Heating Output (kBtu/h)	Supp Heat Output (kBtu/h)	Efficiency Unit	Efficiency	Total Cooling Output (kBtu/h)	Efficiency Unit	Efficiency	Economizer Type (if present)	Status ¹
CU/EC/F-A.1	Single Zone Air Conditioner (SZAC) Air System	1	80	0	AFUE	0	60	EER SEER	12.2 15	Differential DB	N
CU/EC/F-B.1	Single Zone Air Conditioner (SZAC) Air System	1	50	0	AFUE	0	34.56	EER SEER	12.2 15.5	Differential DB	N
CU/EC/F-B.2	Single Zone Air Conditioner (SZAC) Air System	1	50	0	AFUE	0	34.56	EER SEER	12.2 15.5	Differential DB	N

¹ Status: N - New, A - Altered, E - Existing

CA Building Energy Efficiency Standards - 2022 Nonresidential ComplianceReport Version: 2022.0.000Schema Version: rev 20220601Report Generated: 2025-09-10 14:33:35Compliance ID: EnergyPro-4917-0925-0243

CERTIFICATE OF COMPLIANCE - NONRESIDENTIAL PERFORMANCE COMPLIANCE METHODNRCC-PRF-E

Nonresidential Performance Compliance Method(Page 2 of 17)

B. PROJECT SUMMARY

Table B shows which building components are included in the performance calculation. If indicated as not included, the project must show compliance prescriptively if within the permit application.

Building Components Complying via Performance				Building Components Complying Prescriptively	
Envelope (See Table G)	Nonres	Not Included	Solar Thermal Water Heating (See Table I3)	☐ Performance ☒ Not Included	The following building components are ONLY eligible for prescriptive compliance and should be documented on the NRCC form listed if within the scope of the permit application (i.e. compliance will not be shown on the NRCC-PRF-E).
Mechanical (See Table H)	Nonres	Performance	Covered Process: Commercial Kitchens (see Table J)	☐ Performance ☒ Not Included	Indoor Lighting (Unconditioned) 140.6 & 170.2(e)NRCC-LTH-E is required
Domestic Hot Water (See Table I)	Nonres	Not Included	Covered Process: Laboratory Exhaust (see Table J)	☐ Performance ☒ Not Included	Outdoor Lighting 140.7 & 170.2(e)NRCC-LTO-E is required
Lighting (Indoor Conditioned, see Table K)	Nonres	Not Included	Photovoltaics (see Table F)	☐ Performance ☒ Not Included	Sign Lighting 140.8 & 170.2(e)NRCC-LTS-E is required
	MultiFam	Not Included		☐ Performance ☒ Not Included	Electrical power systems, commissioning, solar ready, elevator and escalator requirements are mandatory and should be documented on the NRCC form listed if applicable (i.e. compliance will not be shown on the NRCC-PRF-E)
			Battery (see Table F)	☐ Performance ☒ Not Included	Electrical Power Distribution 110.11NRCC-ELC-E is required
					Commissioning 120.8NRCC-CXR-E is required
					Solar and Battery 110.10NRCC-SAB-E is required

CA Building Energy Efficiency Standards - 2022 Nonresidential ComplianceReport Version: 2022.0.000Schema Version: rev 20220601Report Generated: 2025-09-10 14:33:35Compliance ID: EnergyPro-4917-0925-0243

CERTIFICATE OF COMPLIANCE - NONRESIDENTIAL PERFORMANCE COMPLIANCE METHODNRCC-PRF-E

Nonresidential Performance Compliance Method(Page 5 of 17)

C3. TDV ENERGY RESULTS FOR NON-REGULATED COMPONENTS¹

Non-Regulated Energy Component	Standard Design (TDV)	Proposed Design (TDV)	Compliance Margin (TDV) ¹
Receptacle	65.88	65.88	---
Process	1.24	1.24	---
Other Ltg	---	---	---
Process Motors	---	---	---
TOTAL (TOTAL COMPLIANCE + NON-REGULATED COMPONENTS)	283.88	250.65	33.23 (11.7%)

¹ Notes: This table is not used for Energy Code Compliance.

C6. "ABOVE CODE" QUALIFICATIONS

☐ This project is pursuing CalGreen Tier 1☐ This project is pursuing CalGreen Tier 2

CA Building Energy Efficiency Standards - 2022 Nonresidential ComplianceReport Version: 2022.0.000Schema Version: rev 20220601Report Generated: 2025-09-10 14:33:35Compliance ID: EnergyPro-4917-0925-0243

CERTIFICATE OF COMPLIANCE - NONRESIDENTIAL PERFORMANCE COMPLIANCE METHODNRCC-PRF-E

Nonresidential Performance Compliance Method(Page 8 of 17)

H1. DRY SYSTEM EQUIPMENT (FURNACES, AIR HANDLING UNITS, HEAT PUMPS, VRF, ECONOMIZERS ETC.)

01	02	03	04	05	06	07	08	09	10	11	12
Equipment Name	Equipment Type	Qty	Total Heating Output (kBtu/h)	Supp Heat Output (kBtu/h)	Efficiency Unit	Efficiency	Total Cooling Output (kBtu/h)	Efficiency Unit	Efficiency	Economizer Type (if present)	Status ¹
CU/EC/F-C.1	Single Zone Air Conditioner (SZAC) Air System	1	50	0	AFUE	0	34.56	EER SEER	12.2 15.5	Differential DB	N
CU/EC/F-C.2	Single Zone Air Conditioner (SZAC) Air System	1	50	0	AFUE	0	34.56	EER SEER	12.2 15.5	Differential DB	N
CU/EC/F-C.3	Single Zone Air Conditioner (SZAC) Air System	1	50	0	AFUE	0	34.56	EER SEER	12.2 15.5	Differential DB	N
CU/EC/F-C.4	Single Zone Air Conditioner (SZAC) Air System	1	50	0	AFUE	0	34.56	EER SEER	12.2 15.5	Differential DB	N
CU/EC/F-C.5	Single Zone Air Conditioner (SZAC) Air System	1	50	0	AFUE	0	34.56	EER SEER	12.2 15.5	Differential DB	N
CU/EC/F-C.6	Single Zone Air Conditioner (SZAC) Air System	1	50	0	AFUE	0	34.56	EER SEER	12.2 15.5	Differential DB	N
CU/EC/F-D.1	Single Zone Air Conditioner (SZAC) Air System	1	50	0	AFUE	0	34.56	EER SEER	12.2 15.5	Differential DB	N
CU/EC/F-D.2	Single Zone Air Conditioner (SZAC) Air System	1	50	0	AFUE	0	34.56	EER SEER	12.2 15.5	Differential DB	N

¹ Status: N - New, A - Altered, E - Existing

CA Building Energy Efficiency Standards - 2022 Nonresidential ComplianceReport Version: 2022.0.000Schema Version: rev 20220601Report Generated: 2025-09-10 14:33:35Compliance ID: EnergyPro-4917-0925-0243

CERTIFICATE OF COMPLIANCE - NONRESIDENTIAL PERFORMANCE COMPLIANCE METHODNRCC-PRF-E

Nonresidential Performance Compliance Method(Page 3 of 17)

C1. COMPLIANCE SUMMARY

COMPLIES¹

	Time Dependent Valuation (TDV)		Source Energy Use
	Efficiency ¹ (kBtu/ft² · yr)	Total ² (kBtu/ft² · yr)	Total ² (kBtu/ft² · yr)
Standard Design	216.76	n/a	n/a
Proposed Design	183.53	n/a	n/a
Compliance Margins	33.23	n/a	n/a
	Pass	n/a	n/a

¹ Efficiency measures include improvements like a better building envelope and more efficient equipment
² Compliance Totals include efficiency, photovoltaics and batteries
³ New Construction, Complete Addition Scope: Building complies when all efficiency and total compliance margins are greater than or equal to zero and unmet load hour limits are not exceeded
Existing, Addition and Alteration Scope: Building complies when efficiency compliance margin is greater than or equal to zero and unmet load hour limits are not exceeded

CA Building Energy Efficiency Standards - 2022 Nonresidential ComplianceReport Version: 2022.0.000Schema Version: rev 20220601Report Generated: 2025-09-10 14:33:35Compliance ID: EnergyPro-4917-0925-0243

CERTIFICATE OF COMPLIANCE - NONRESIDENTIAL PERFORMANCE COMPLIANCE METHODNRCC-PRF-E

Nonresidential Performance Compliance Method(Page 6 of 17)

C7. ENERGY USE SUMMARY

Energy Component	Standard Design Site (MWh)	Proposed Design Site (MWh)	Margin (MWh)	Standard Design Site (MBtu)	Proposed Design Site (MBtu)	Margin (MBtu)
Space Heating	---	---	---	124.3	50.2	74.1
Space Cooling	13.1	6	7.1	---	---	---
Indoor Fans	69.9	63.2	6.7	---	---	---
Heat Rejection	---	---	---	---	---	---
Pumps & Misc.	---	---	---	---	---	---
Domestic Hot Water	18.4	18.4	0	---	---	---
Indoor Lighting	23.6	23.6	0	---	---	---
Flexibility	---	---	---	---	---	---
EFFICIENCY TOTAL	125	111.2	13.8	124.3	50.2	74.1
Photovoltaics	---	---	---	---	---	---
Batteries	---	---	---	---	---	---
ENERGY USE SUBTOTAL	125	111.2	13.8	124.3	50.2	74.1
Receptacle	48.4	48.4	0	---	---	---
Process	0.8	0.8	0	---	---	---
Other Ltg	---	---	---	---	---	---
Process Motors	---	---	---	---	---	---
ENERGY USE TOTAL	174.2	160.4	13.8	124.3	50.2	74.1

CA Building Energy Efficiency Standards - 2022 Nonresidential ComplianceReport Version: 2022.0.000Schema Version: rev 20220601Report Generated: 2025-09-10 14:33:35Compliance ID: EnergyPro-4917-0925-0243

CERTIFICATE OF COMPLIANCE - NONRESIDENTIAL PERFORMANCE COMPLIANCE METHODNRCC-PRF-E

Nonresidential Performance Compliance Method(Page 9 of 17)


H1. DRY SYSTEM EQUIPMENT (FURNACES, AIR HANDLING UNITS, HEAT PUMPS, VRF, ECONOMIZERS ETC.)

01	02	03	04	05	06	07	08	09	10	11	12
Equipment Name	Equipment Type	Qty	Total Heating Output (kBtu/h)	Supp Heat Output (kBtu/h)	Efficiency Unit	Efficiency	Total Cooling Output (kBtu/h)	Efficiency Unit	Efficiency	Economizer Type (if present)	Status ¹
CU/EC/F-D.3	Single Zone Air Conditioner (SZAC) Air System	1	50	0	AFUE	0	34.56	EER SEER	12.2 15.5	Differential DB	N
CU/EC/F-D.4	Single Zone Air Conditioner (SZAC) Air System	1	50	0	AFUE	0	34.56	EER SEER	12.2 15.5	Differential DB	N
CU/EC/F-D.5	Single Zone Air Conditioner (SZAC) Air System	1	50	0	AFUE	0	34.56	EER SEER	12.2 15.5	Differential DB	N
CU/EC/F-D.6	Single Zone Air Conditioner (SZAC) Air System	1	50	0	AFUE	0	34.56	EER SEER	12.2 15.5	Differential DB	N
CU/EC/F-E.1 & EC/F-E.2	Single Zone Air Conditioner (SZAC) Air System	2	80	0	AFUE	0	60	EER SEER	12.2 15	Differential DB	N
CU/EC/F-E.3	Single Zone Air Conditioner (SZAC) Air System	1	50	0	AFUE	0	34.56	EER SEER	12.2 15.5	Differential DB	N

¹ Status: N - New, A - Altered, E - Existing

CA Building Energy Efficiency Standards - 2022 Nonresidential ComplianceReport Version: 2022.0.000Schema Version: rev 20220601Report Generated: 2025-09-10 14:33:35Compliance ID: EnergyPro-4917-0925-0243

3/20/2023 3:12:50 PM M:\P - PROJECT\20250902-25-0001 SFUSD SKYLINE ES\02_MECH

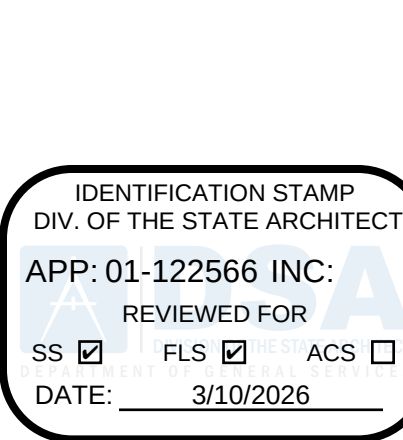

#	Revisions
Delta	Date Revisions By

CERTIFICATE OF COMPLIANCE - NONRESIDENTIAL PERFORMANCE COMPLIANCE METHOD													NRCC-PRF-E
Nonresidential Performance Compliance Method													(Page 10 of 17)

H3. NONRESIDENTIAL / COMMON USE AREA FAN SYSTEMS SUMMARY												
01	02	03	04	05	06	07	08	09	10	11	12	13
Name or Item Tag	Qty	Design OA CFM	CFM	Power	Power Units	Control	Fan Type	CFM	Power	Power Units	Control	Status ¹
CU/EC/F-A.1	1	597.1	1,720	1	BHP	Constant Vol	N/A	N/A	N/A	N/A	N/A	N
CU/EC/F-B.1	1	194.94	1,200	0.85	BHP	Constant Vol	N/A	N/A	N/A	N/A	N/A	N
CU/EC/F-B.2	1	194.94	1,200	0.85	BHP	Constant Vol	N/A	N/A	N/A	N/A	N/A	N
CU/EC/F-C.1	1	339.72	1,200	0.85	BHP	Constant Vol	N/A	N/A	N/A	N/A	N/A	N
CU/EC/F-C.2	1	338.58	1,200	0.85	BHP	Constant Vol	N/A	N/A	N/A	N/A	N/A	N
CU/EC/F-C.3	1	339.72	800	0.85	BHP	Constant Vol	N/A	N/A	N/A	N/A	N/A	N
CU/EC/F-C.4	1	339.72	800	0.85	BHP	Constant Vol	N/A	N/A	N/A	N/A	N/A	N
CU/EC/F-C.5	1	338.58	800	0.85	BHP	Constant Vol	N/A	N/A	N/A	N/A	N/A	N
CU/EC/F-C.6	1	339.72	800	0.85	BHP	Constant Vol	N/A	N/A	N/A	N/A	N/A	N
CU/EC/F-D.1	1	349.22	800	0.85	BHP	Constant Vol	N/A	N/A	N/A	N/A	N/A	N
CU/EC/F-D.2	1	335.54	1,200	0.85	BHP	Constant Vol	N/A	N/A	N/A	N/A	N/A	N
CU/EC/F-D.3	1	340.86	1,200	0.85	BHP	Constant Vol	N/A	N/A	N/A	N/A	N/A	N
CU/EC/F-D.4	1	341.62	1,200	0.85	BHP	Constant Vol	N/A	N/A	N/A	N/A	N/A	N
CU/EC/F-D.5	1	334.4	1,200	0.85	BHP	Constant Vol	N/A	N/A	N/A	N/A	N/A	N
CU/EC/F-D.6	1	335.54	800	0.85	BHP	Constant Vol	N/A	N/A	N/A	N/A	N/A	N
CU/EC/F-E.1 & EC/F-E.2	2	956	1,720	1	BHP	Constant Vol	N/A	N/A	N/A	N/A	N/A	N
CU/EC/F-E.3	1	282.95	800	0.85	BHP	Constant Vol	N/A	N/A	N/A	N/A	N/A	N

¹ Status: N - New, A - Altered, E - Existing

CA Building Energy Efficiency Standards - 2022 Nonresidential Compliance Report Version: 2022.0.000 Schema Version: rev 20220601 Report Generated: 2025-09-10 14:33:35 Compliance ID: EnergyPro-4917-0925-0243

CERTIFICATE OF COMPLIANCE - NONRESIDENTIAL PERFORMANCE COMPLIANCE METHOD								NRCC-PRF-E
Nonresidential Performance Compliance Method								(Page 11 of 17)

H5. GENERAL EXHAUST FAN SUMMARY							
01	02	03	04	05	06	07	08
System ID	Zone Name	Qty	CFM	Power	Power Units	Continuous Operation?	Status ¹
Kitchen E11120-EF	17-Kitchen E11	1	375	0.25	BHP	No	E

¹ Status: N - New, A - Altered, E - Existing

H8. SYSTEM SPECIAL FEATURES			
01	02	03	04
System Name	Equipment Type	Interlocks per 140.4(n) ¹	Other Special Features and Controls
CU/EC/F-A.1	Single Zone Air Conditioner (SZAC) Air System	N/A	Zone(s) With CO2 Sensor Vent. Control Differential DB
CU/EC/F-B.1	Single Zone Air Conditioner (SZAC) Air System	N/A	Zone(s) With CO2 Sensor Vent. Control Differential DB
CU/EC/F-B.2	Single Zone Air Conditioner (SZAC) Air System	N/A	Zone(s) With CO2 Sensor Vent. Control Differential DB
CU/EC/F-C.1	Single Zone Air Conditioner (SZAC) Air System	N/A	Zone(s) With CO2 Sensor Vent. Control Differential DB
CU/EC/F-C.2	Single Zone Air Conditioner (SZAC) Air System	N/A	Zone(s) With CO2 Sensor Vent. Control Differential DB
CU/EC/F-C.3	Single Zone Air Conditioner (SZAC) Air System	N/A	Zone(s) With CO2 Sensor Vent. Control Differential DB
CU/EC/F-C.4	Single Zone Air Conditioner (SZAC) Air System	N/A	Zone(s) With CO2 Sensor Vent. Control Differential DB
CU/EC/F-C.5	Single Zone Air Conditioner (SZAC) Air System	N/A	Zone(s) With CO2 Sensor Vent. Control Differential DB

Notes: This table includes controls related to the performance path only. For projects using the prescriptive path, mandatory and prescriptive controls requirements are documented on the NRCC-MCH-E.

¹ Yes = interlocks are provided, No = interlocks are not provided, NA means no operable openings.

CA Building Energy Efficiency Standards - 2022 Nonresidential Compliance Report Version: 2022.0.000 Schema Version: rev 20220601 Report Generated: 2025-09-10 14:33:35 Compliance ID: EnergyPro-4917-0925-0243

CERTIFICATE OF COMPLIANCE - NONRESIDENTIAL PERFORMANCE COMPLIANCE METHOD				NRCC-PRF-E
Nonresidential Performance Compliance Method				(Page 12 of 17)

H8. SYSTEM SPECIAL FEATURES			
01	02	03	04
System Name	Equipment Type	Interlocks per 140.4(n) ¹	Other Special Features and Controls
CU/EC/F-C.6	Single Zone Air Conditioner (SZAC) Air System	N/A	Zone(s) With CO2 Sensor Vent. Control Differential DB
CU/EC/F-D.1	Single Zone Air Conditioner (SZAC) Air System	N/A	Zone(s) With CO2 Sensor Vent. Control Differential DB
CU/EC/F-D.2	Single Zone Air Conditioner (SZAC) Air System	N/A	Zone(s) With CO2 Sensor Vent. Control Differential DB
CU/EC/F-D.3	Single Zone Air Conditioner (SZAC) Air System	N/A	Zone(s) With CO2 Sensor Vent. Control Differential DB
CU/EC/F-D.4	Single Zone Air Conditioner (SZAC) Air System	N/A	Zone(s) With CO2 Sensor Vent. Control Differential DB
CU/EC/F-D.5	Single Zone Air Conditioner (SZAC) Air System	N/A	Zone(s) With CO2 Sensor Vent. Control Differential DB
CU/EC/F-D.6	Single Zone Air Conditioner (SZAC) Air System	N/A	Zone(s) With CO2 Sensor Vent. Control Differential DB
CU/EC/F-E.1 & EC/F-E.2	Single Zone Air Conditioner (SZAC) Air System	N/A	Zone(s) With CO2 Sensor Vent. Control Differential DB
CU/EC/F-E.3	Single Zone Air Conditioner (SZAC) Air System	N/A	Zone(s) With CO2 Sensor Vent. Control Differential DB

Notes: This table includes controls related to the performance path only. For projects using the prescriptive path, mandatory and prescriptive controls requirements are documented on the NRCC-MCH-E.

¹ Yes = interlocks are provided, No = interlocks are not provided, NA means no operable openings.

CA Building Energy Efficiency Standards - 2022 Nonresidential Compliance Report Version: 2022.0.000 Schema Version: rev 20220601 Report Generated: 2025-09-10 14:33:35 Compliance ID: EnergyPro-4917-0925-0243

CERTIFICATE OF COMPLIANCE - NONRESIDENTIAL PERFORMANCE COMPLIANCE METHOD													NRCC-PRF-E
Nonresidential Performance Compliance Method													(Page 13 of 17)

H9. NONRESIDENTIAL / COMMON USE AREA & HOTEL/MOTEL VENTILATION						
01	02	03	04	05	06	07
Zone Name	Ventilation Function	# of People	Supply OA CFM	Exhaust CFM	Conditioned Area (sf)	DCV or Occupant Sensor Controls, or Both
1-Principal A3	Office - Office space Education - Multituse assembly General - Corridors Office - Reception areas General - Conference/meeting General - Break rooms	47.5	597.1	0	1855	DCV
2-Kindergarten K1	Education - Classrooms (ages 5-8)	12.82	194.94	0	513	DCV
3-Kindergarten K2	Education - Classrooms (ages 5-8)	12.82	194.94	0	513	DCV
4-Classroom 8	Education - Classrooms (ages 5-8)	22.35	339.72	0	894	DCV
5-Classroom 6	Education - Classrooms (ages 5-8)	22.27	338.58	0	891	DCV
6-Classroom 7	Education - Classrooms (ages 5-8)	22.35	339.72	0	894	DCV
7-Classroom 8	Education - Classrooms (ages 5-8)	22.35	339.72	0	894	DCV
8-Classroom 5	Education - Classrooms (ages 5-8)	22.27	338.58	0	891	DCV
9-Classroom 4	Education - Classrooms (ages 5-8)	22.35	339.72	0	894	DCV
10-Classroom 9	Education - Classrooms (ages 5-8)	22.98	349.22	0	919	DCV
11-Classroom 12	Education - Classrooms (ages 5-8)	22.07	335.54	0	883	DCV

CA Building Energy Efficiency Standards - 2022 Nonresidential Compliance Report Version: 2022.0.000 Schema Version: rev 20220601 Report Generated: 2025-09-10 14:33:35 Compliance ID: EnergyPro-4917-0925-0243

CERTIFICATE OF COMPLIANCE - NONRESIDENTIAL PERFORMANCE COMPLIANCE METHOD													NRCC-PRF-E
Nonresidential Performance Compliance Method													(Page 14 of 17)

H9. NONRESIDENTIAL / COMMON USE AREA & HOTEL/MOTEL VENTILATION						
01	02	03	04	05	06	07
Zone Name	Ventilation Function	# of People	Supply OA CFM	Exhaust CFM	Conditioned Area (sf)	DCV or Occupant Sensor Controls, or Both
12-Classroom 13	Education - Classrooms (ages 5-8)	22.43	340.86	0	897	DCV
13-Classroom 14	Education - Classrooms (ages 5-8)	22.48	341.62	0	899	DCV
14-Classroom 11	Education - Classrooms (ages 5-8)	22	334.4	0	880	DCV
15-Classroom 10	Education - Classrooms (ages 5-8)	22.07	335.54	0	883	DCV
16-Multi-Use Room E1	Education - Multituse assembly	127.47	1912	0	3824	DCV
17-Kitchen E11	Food Service - Kitchen (cooking) Food Service - Cafeteria/fast-food dining	26.56	282.95	375	925	DCV

H11. ZONAL SYSTEM AND TERMINAL UNIT SUMMARY											
01	02	03	04	05	06	07	08	09	10	11	12
System ID	System Type	Qty	Rated Capacity (kBtu/h)		Airflow (cfm)			Fan			VSD
			Heating	Cooling	Design	Min.	Min. Ratio	Power	Power Units	Cycles	
1-Principal A3-Trm	Uncontrolled	1	N/A	N/A	1,720	N/A	0	N/A	N/A	N/A	☐
2-Kindergarten K3-Trm	Uncontrolled	1	N/A	N/A	1,200	N/A	0	N/A	N/A	N/A	☐
3-Kindergarten K2-Trm	Uncontrolled	1	N/A	N/A	1,200	N/A	0	N/A	N/A	N/A	☐
4-Classroom 8-Trm	Uncontrolled	1	N/A	N/A	1,200	N/A	0	N/A	N/A	N/A	☐
5-Classroom 6-Trm	Uncontrolled	1	N/A	N/A	1,200	N/A	0	N/A	N/A	N/A	☐
6-Classroom 7-Trm	Uncontrolled	1	N/A	N/A	800	N/A	0	N/A	N/A	N/A	☐
7-Classroom 8-Trm	Uncontrolled	1	N/A	N/A	800	N/A	0	N/A	N/A	N/A	☐

CA Building Energy Efficiency Standards - 2022 Nonresidential Compliance Report Version: 2022.0.000 Schema Version: rev 20220601 Report Generated: 2025-09-10 14:33:35 Compliance ID: EnergyPro-4917-0925-0243

CERTIFICATE OF COMPLIANCE - NONRESIDENTIAL PERFORMANCE COMPLIANCE METHOD													NRCC-PRF-E
Nonresidential Performance Compliance Method													(Page 15 of 17)

H11. ZONAL SYSTEM AND TERMINAL UNIT SUMMARY											
01	02	03	04	05	06	07	08	09	10	11	12
System ID	System Type	Qty	Rated Capacity (kBtu/h)		Airflow (cfm)			Fan			VSD
			Heating	Cooling	Design	Min.	Min. Ratio	Power	Power Units	Cycles	
8-Classroom 5-Trm	Uncontrolled	1	N/A	N/A	800	N/A	0	N/A	N/A	N/A	☐
9-Classroom 4-Trm	Uncontrolled	1	N/A	N/A	800	N/A	0	N/A	N/A	N/A	☐
10-Classroom 9-Trm	Uncontrolled	1	N/A	N/A	800	N/A	0	N/A	N/A	N/A	☐
11-Classroom 12-Trm	Uncontrolled	1	N/A	N/A	1,200	N/A	0	N/A	N/A	N/A	☐
12-Classroom 13-Trm	Uncontrolled	1	N/A	N/A	1,200	N/A	0	N/A	N/A	N/A	☐
13-Classroom 14-Trm	Uncontrolled	1	N/A	N/A	1,200	N/A	0	N/A	N/A	N/A	☐
14-Classroom 11-Trm	Uncontrolled	1	N/A	N/A	1,200	N/A	0	N/A	N/A	N/A	☐
15-Classroom 10-Trm	Uncontrolled	1	N/A	N/A	800	N/A	0	N/A	N/A	N/A	☐
16-Multi-Use Room E1-Trm	Uncontrolled	2	N/A	N/A	3,440	N/A	0	N/A	N/A	N/A	☐
17-Kitchen E11-Trm	Uncontrolled	1	N/A	N/A	800	N/A	0	N/A	N/A	N/A	☐

L. DECLARATION OF REQUIRED CERTIFICATES OF INSTALLATION	
Selections made by Documentation Author indicate which Certificates of Installation must be submitted for the features to be recognized for compliance. These documents must be retained and provided to the building inspector during construction and can be found online	
Building Component	Form/Title
Mechanical	NRCC-MCH-E - For all buildings with Mechanical Systems

M. DECLARATION OF REQUIRED CERTIFICATES OF ACCEPTANCE	
Selections made by Documentation Author indicate which Certificates of Acceptance must be submitted for the features to be recognized for compliance. These documents must be provided to the building inspector during construction and must be completed through an Acceptance Test Technician Certification Provider (ATTCP).	
Building Component	Form/Title & System Name(s)
Mechanical	NRCA-MCH-02-A - Outdoor Air must be submitted for all newly installed HVAC units. Note: MCH-02-A can be performed in conjunction with MCH-07-A Supply Fan VFD Acceptance (if applicable) since testing activities overlap CU/EC/F-A.1, CU/EC/F-B.1, CU/EC/F-B.2, CU/EC/F-C.1, CU/EC/F-C.2, CU/EC/F-C.3, CU/EC/F-C.4, CU/EC/F-C.5, CU/EC/F-C.6, CU/EC/F-D.1, CU/EC/F-D.2, CU/EC/F-D.3, CU/EC/F-D.4, CU/EC/F-D.5, CU/EC/F-D.6, CU/EC/F-E.1 & EC/F-E.2 and CU/EC/F-E.3.

CA Building Energy Efficiency Standards - 2022 Nonresidential Compliance Report Version: 2022.0.000 Schema Version: rev 20220601 Report Generated: 2025-09-10 14:33:35 Compliance ID: EnergyPro-4917-0925-0243

CERTIFICATE OF COMPLIANCE - NONRESIDENTIAL PERFORMANCE COMPLIANCE METHOD													NRCC-PRF-E
Nonresidential Performance Compliance Method													(Page 16 of 17)

N. DECLARATION OF REQUIRED CERTIFICATES OF ACCEPTANCE	
Selections made by Documentation Author indicate which Certificates of Acceptance must be submitted for the features to be recognized for compliance. These documents must be provided to the building inspector during construction and must be completed through an Acceptance Test Technician Certification Provider (ATTCP).	
Building Component	Form/Title & System Name(s)
Mechanical	NRCA-MCH-03-A - Constant Volume Single Zone HVAC CU/EC/F-A.1, CU/EC/F-B.1, CU/EC/F-B.2, CU/EC/F-C.1, CU/EC/F-C.2, CU/EC/F-C.3, CU/EC/F-C.4, CU/EC/F-C.5, CU/EC/F-C.6, CU/EC/F-D.1, CU/EC/F-D.2, CU/EC/F-D.3, CU/EC/F-D.4, CU/EC/F-D.5, CU/EC/F-D.6, CU/EC/F-E.1 & EC/F-E.2 and CU/EC/F-E.3.
Mechanical	NRCA-MCH-05-A - Air Economizer Controls CU/EC/F-A.1, CU/EC/F-B.1, CU/EC/F-B.2, CU/EC/F-C.1, CU/EC/F-C.2, CU/EC/F-C.3, CU/EC/F-C.4, CU/EC/F-C.5, CU/EC/F-C.6, CU/EC/F-D.1, CU/EC/F-D.2, CU/EC/F-D.3, CU/EC/F-D.4, CU/EC/F-D.5, CU/EC/F-D.6, CU/EC/F-E.1 & EC/F-E.2 and CU/EC/F-E.3.
Mechanical	NRCA-MCH-06-A Demand Control Ventilation Systems must be submitted for all systems required to employ demand controlled ventilation (refer to) can vary outside ventilation flow rates based on maintaining interior carbon dioxide (CO2) concentration setpoints. CU/EC/F-A.1, CU/EC/F-B.1, CU/EC/F-B.2, CU/EC/F-C.1, CU/EC/F-C.2, CU/EC/F-C.3, CU/EC/F-C.4, CU/EC/F-C.5, CU/EC/F-C.6, CU/EC/F-D.1, CU/EC/F-D.2, CU/EC/F-D.3, CU/EC/F-D.4, CU/EC/F-D.5, CU/EC/F-D.6, CU/EC/F-E.1 & EC/F-E.2 and CU/EC/F-E.3.
Mechanical	NRCA-MCH-12-A FDD for Packaged Direct Expansion Units CU/EC/F-A.1, CU/EC/F-B.1, CU/EC/F-B.2, CU/EC/F-C.1, CU/EC/F-C.2, CU/EC/F-C.3, CU/EC/F-C.4, CU/EC/F-C.5, CU/EC/F-C.6, CU/EC/F-D.1, CU/EC/F-D.2, CU/EC/F-D.3, CU/EC/F-D.4, CU/EC/F-D.5, CU/EC/F-D.6,



IF THIS SHEET IS NOT 30"x42" . IT IS A
REDUCED PRINT; SCALE ACCORDINGLY

IDENTIFICATION STAMP
DIV. OF THE STATE ARCHITECT

APP: 01-122566 INC:

REVIEWED FOR


SS ☒ FLS ☒ ACS ☐

DATE: 3/10/2026



Revisions	Delta	Date	Revisions	By
-----------	-------	------	-----------	----

KEY PLAN

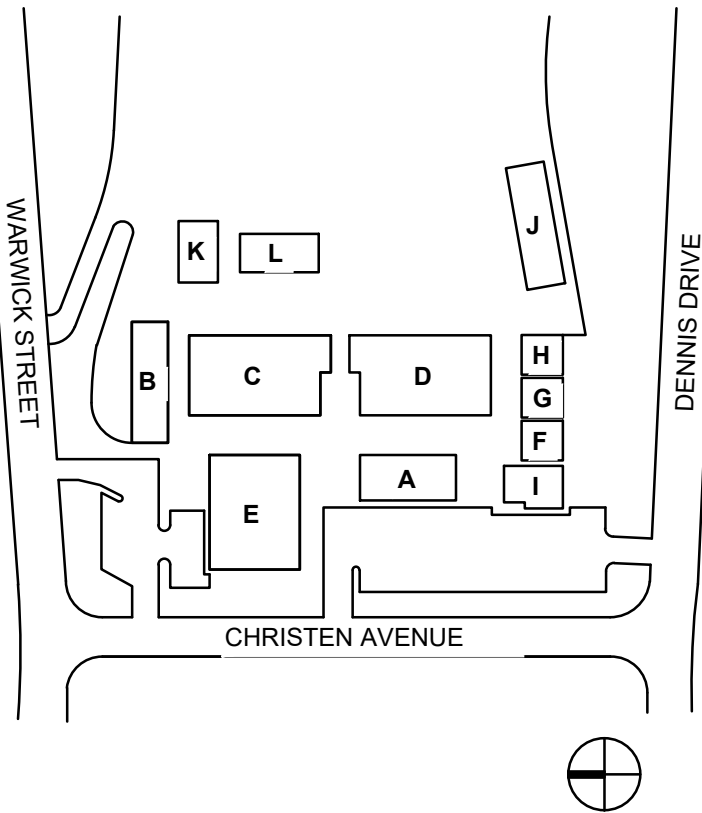

WORM

Electrical Consultants Incorporated
3397 Mt. Diablo Blvd., Suite C
Lafayette, CA 94549
Tel: 925-385-0549
25-004

This document is the property of the Owner and is not to be used without their written permission.



HY ARCHITECTS JOB NUMBER XXXX

Facility

SKYLINE ELEMENTARY SCHOOL
55 CHRISTEN AVE, DALY CITY, CA 94015

Project

HVAC REPLACEMENT

Sheet Title

ELECTRICAL SYMBOLS, NOTES AND
SCHEDULES

Client Project Number: XXXX

Scale: AS NOTED

Drawn By: DAM

Checked By: TLK

Issue Date: 09/15/25

Revit Version: 2023

E0.01

GENERAL ELECTRICAL NOTES

- ELECTRICAL CONTRACTOR IS TO PROVIDE LABOR, MATERIALS, TRANSPORTATION, EQUIPMENT, RELATED HAND TOOLS, SPECIAL AND OCCASIONAL SERVICES TO CONSTRUCT AND INSTALL THE COMPLETE ELECTRICAL SYSTEM AS SPECIFIED AND SHOWN ON THE PLANS.
- MOUNTING HEIGHTS SHALL BE A MAXIMUM +48" TO TOP OF BOX OR MINIMUM 15" TO BOTTOM OF BOX PER CBC 1142A. ALL MOUNTING HEIGHTS SHALL BE AS SHOWN ON SYMBOL LIST UNLESS OTHERWISE NOTED ON DRAWINGS.
- BONDING JUMPERS SHALL BE INSTALLED TO INSURE CONTINUITY WHERE CONDUIT CONNECTIONS AT CONCENTRIC KNOCKOUTS ARE TO SERVE AS A GROUND.
- PROVIDE GREEN THWN COPPER GROUND WIRE FROM PANELBOARD GROUND BUS TO ALL BRANCH CIRCUITS.
- THE ELECTRICIAN SHALL CHECK THE TIGHTNESS OF ALL PANELBOARD BUSES AND CIRCUIT BREAKER LUGS. COMPLETELY VACUUM AND CLEAN INTERIOR OF EQUIPMENT PRIOR TO TURN OVER TO THE OWNER.
- ALL NEW AND EXISTING PANELBOARDS AND SWITCHBOARDS SHALL BE PROVIDED WITH NEW TYPEWRITTEN DIRECTORIES TO IDENTIFY THE LOCATION OF EACH LOAD SERVED.
- ALL EQUIPMENT SHALL BE U.L. LISTED AND INSTALLED AS PER LISTING OR LABELING (I.E. MAX. FUSE SIZES MEAN FUSE PROTECTION REQUIRED).
- CONTRACTOR TO COORDINATE ALL NEW WORK WITH ALL OTHER TRADES FOR A SMOOTH FLOW OF INSTALLATION WORK.
- ELECTRICAL CONTRACTOR SHALL BE RESPONSIBLE FOR DAMAGES TO ALL WALLS, FLOORS AND CEILINGS INCURRED DURING ELECTRICAL CONSTRUCTION. IF DAMAGE OCCURS DURING ELECTRICAL CONSTRUCTION, THE ELECTRICAL CONTRACTOR SHALL COORDINATE WITH GENERAL CONTRACTOR TO PATCH, PAINT AND REPAIR TO MATCH EXISTING CONDITIONS.
- COORDINATE EQUIPMENT LOCATIONS AND ELECTRICAL REQUIREMENTS OF ALL EQUIPMENT REQUIRING ELECTRICAL HOOK-UP WITH CONTRACTOR RESPONSIBLE FOR PROVIDING EQUIPMENT AND EQUIPMENT MANUFACTURER DATA SHEETS.
- ALL CORRIDOR AND EXTERIOR WALL PENETRATIONS FOR PIPES, CONDUITS, ETC., IN WALLS REQUIRING PROTECTED OPENINGS SHALL BE FIRE STOPPED. FIRE STOP MATERIAL SHALL BE A TESTED ASSEMBLY APPROVED BY THE CALIFORNIA STATE FIRE MARSHAL.
- ELECTRICAL CONTRACTOR SHALL REVIEW MECHANICAL AND PLUMBING CONTRACT DRAWINGS AND VERIFY ALL MECHANICAL EQUIPMENT LOCATIONS, MOTOR SIZES AND CONTROL WIRING REQUIREMENTS WITH MECHANICAL CONTRACTOR AND MECHANICAL EQUIPMENT SUPPLIERS AND MANUFACTURERS PRIOR TO INSTALLATION OF ELECTRICAL CONNECTIONS.
- ALL CONTROL DEVICES TO BE USED BY THE OCCUPANT OF THE ROOM OR AREA SHALL BE INSTALLED AT A MINIMUM OF 36" C/L TO A MAXIMUM OF 48" TO TOP OF BOX FROM THE FINISHED FLOOR.
- ELECTRICAL DRAWINGS ARE DIAGRAMMATIC AND ALTHOUGH THE SIZE AND LOCATIONS OF EQUIPMENT IS SHOWN TO SCALE WHEREVER POSSIBLE, CONTRACTOR SHALL MAKE USE OF MANUFACTURER'S OR OWNER'S DATA AVAILABLE AND/OR VERIFY DATA IN THE FIELD FOR PROVIDING AND INSTALLING CORRECT CABLE LENGTHS.
- ALL EQUIPMENT MUST BE LISTED, LABELED, OR CERTIFIED BY A NATIONAL RECOGNIZED TESTING LABORATORY (NRTL).
- ELECTRICAL CONTRACTOR SHALL COORDINATE WITH ALL TRADES TO KEEP ELECTRICAL ROOMS EXCLUSIVELY DEDICATED TO PANELBOARDS, SIGNAL AND OTHER ELECTRICAL EQUIPMENT. NO PLUMBING, PIPING OR MECHANICAL DUCTS SHALL RUN OVER ELECTRICAL PANEL OR OTHER ELECTRICAL EQUIPMENT PER C.E.C. 110-26(f).
- ALL SWITCHES AND RECEPTACLES SHALL BE PROVIDED WITH 'BROTHER' LABELING SYSTEM TO IDENTIFY THE PANEL AND CIRCUIT NUMBER OF EACH OUTLET. COLOR TO BE 3/8" HIGH BLACK ON TRANSPARENT TAPE.
- ALL CABINETS, DISCONNECT SWITCHES, PULLBOXES, AND TERMINAL BOXES SHALL BE PROVIDED WITH LABELING SYSTEM TO IDENTIFY THE PANEL AND ITS USE. SEE SPECIFICATIONS FOR REQUIREMENTS.
- MAINTAIN "AS-BUILT" RECORDS AT ALL TIMES, SHOWING EXACT LOCATION OF ALL UNDERGROUND AND/OR CONCEALED CONDUITS AND SERVICES INSTALLED UNDER THIS CONTRACT, INCLUDING CIRCUIT IDENTIFICATION WHERE APPLICABLE. PROVIDE OWNER WITH "AS-BUILT" DOCUMENTS AS INDICATED IN THE PROJECT MANUAL.
- DRAWINGS INDICATE THE LOCATION OF DEVICES, FIXTURES AND EQUIPMENT AND THE CIRCUIT NUMBER AND PANEL DESIGNATION WHICH SUPPLIES THEM. THE CONTRACTOR SHALL VERIFY WITH ARCHITECT/VENDORS AND COORDINATE ALL LOCATIONS PRIOR TO INSTALLATION. CONTRACTOR SHALL BE RESPONSIBLE FOR COMPLETELY CONNECTING ALL ELECTRICAL DEVICES TO CIRCUITS INDICATED ON THE DRAWINGS.
- ALL EQUIPMENT GROUNDING SHALL CONFORM TO ARTICLE 250 OF THE NATIONAL ELECTRIC CODE, LATEST EDITION.
- ALL EXTERIOR CONDUIT ABOVE GRADE INCLUDING ALL ROOF MOUNTED CONDUIT, SHALL BE RIGID GALVANIZED STEEL, U.O.N. COAT ALL EXPOSED THREADS WITH GALVANIZING PAINT.
- ALL CONDUIT SHALL BE CONCEALED, UNLESS OTHERWISE NOTED.
- ALL UNDERGROUND CONDUIT RUNS SHALL BE SEALED TO PREVENT GAS/MOISTURE ENTERING THE PIPE PER ARTICLE 230-8, 300.5 AND 300.50E.
- PROVIDE EXPANSION FITTINGS AND/OR CONDUIT FLEX TO CONDUITS PASSING THROUGH STRUCTURAL EXPANSION JOINT SYSTEM. VERIFY/COORDINATE WITH ARCHITECT FOR LOCATION.
- ALL RACEWAY PASSING THROUGH EXPANSION JOINT AREA SHALL BE PROVIDED WITH EXPANSION JOINT FITTINGS AND/OR FLEX CONDUIT AS REQUIRED.
- ALL EXTERIOR MOUNTED GFI RECEPTACLE OUTLETS TO BE PROVIDED WITH LOCKABLE COVERS, TAYMAC MX3200.
- ALL EQUIPMENT/COMPONENTS/DEVICES INSTALLED OUTDOOR SHALL BE U.L. LISTED FOR WET LOCATION.
- THE CONTRACTOR SHALL VERIFY WITH THE ARCHITECTURAL DRAWINGS ALL LOCATIONS AND DIMENSIONS OF DEVICES/EQUIPMENT PRIOR TO ROUGH-IN.
- ALL DIVISION 23 EQUIPMENT LOW VOLTAGE CONTROL WIRING SHALL BE PROVIDED AND INSTALLED BY DIVISION 23 U.O.N. PROVIDE CONDUIT WHERE REQUIRED BY DIV 23.
- ALL CONDUIT STUB OUTS AND CONDUITS TERMINATING TO A J-BOX, CABINET, AND THE LIKE SHALL BE PROVIDED WITH INSULATED THROAT. BOX OR CABINET COVER SHALL BE LABELED AS TO USE.

MEP COMPONENT ANCHORAGE NOTE

APPLICABLE CODE: 2022 CBC PER IR 16-13

ALL MECHANICAL, PLUMBING, AND ELECTRICAL COMPONENTS SHALL BE ANCHORED AND INSTALLED PER THE DETAILS ON THE DSA APPROVED CONSTRUCTION DOCUMENTS. THE FOLLOWING COMPONENTS SHALL BE ANCHORED OR BRACED TO MEET THE FORCE AND DISPLACEMENT REQUIREMENTS PRESCRIBED IN THE 2022 CBC, SECTIONS 1617A.1.18 THROUGH 1617A.1.26 AND ASCE 7-16 CHAPTER 13, 26 AND 30.

- ALL PERMANENT EQUIPMENT AND COMPONENTS.
- TEMPORARY, MOVABLE OR MOBILE EQUIPMENT THAT IS PERMANENTLY ATTACHED (E.G. HARD WIRED) TO THE BUILDING UTILITY SERVICES SUCH AS ELECTRICITY, GAS OR WATER. 'PERMANENTLY ATTACHED' SHALL INCLUDE ALL ELECTRICAL CONNECTIONS EXCEPT PLUGS FOR 110/220 VOLT RECEPTACLES HAVING FLEXIBLE CABLE.
- TEMPORARY, MOVABLE OR MOBILE EQUIPMENT WHICH IS HEAVIER THAN 400 POUNDS OR HAS A CENTER OF MASS LOCATED 4 FEET OR MORE ABOVE THE ADJACENT FLOOR OR ROOF LEVEL THAT DIRECTLY SUPPORT THE COMPONENT IS REQUIRED TO BE RESTRAINED IN A MANNER APPROVED BY DSA.

THE FOLLOWING MECHANICAL AND ELECTRICAL COMPONENTS SHALL BE POSITIVELY ATTACHED TO THE STRUCTURE BUT NEED NOT DEMONSTRATE DESIGN COMPLIANCE WITH THE REFERENCES NOTED ABOVE. THESE COMPONENTS SHALL HAVE FLEXIBLE CONNECTIONS PROVIDED BETWEEN THE COMPONENT AND ASSOCIATED DUCTWORK, PIPING AND CONDUIT. FLEXIBLE CONNECTIONS MUST ALLOW MOVEMENT IN BOTH TRANSVERSE AND LONGITUDINAL DIRECTIONS:

- COMPONENTS WEIGHING LESS THAN 400 POUNDS AND HAVE A CENTER OF MASS LOCATED 4 FEET OR LESS ABOVE THE ADJACENT FLOOR OR ROOF LEVEL THAT DIRECTLY SUPPORT THE COMPONENT.
- COMPONENTS WEIGHING LESS THAN 20 POUNDS OR IN THE CASE OF DISTRIBUTED SYSTEMS, LESS THAN 5 POUNDS PER FOOT, WHICH ARE SUSPENDED FROM A ROOF OR FLOOR OR HUNG FROM A WALL.

THE ANCHORAGE OF ALL MECHANICAL, ELECTRICAL AND PLUMBING COMPONENTS SHALL BE SUBJECT TO THE APPROVAL OF THE DESIGN PROFESSIONAL IN GENERAL RESPONSIBLE CHARGE OR STRUCTURAL ENGINEER DELEGATED RESPONSIBILITY AND ACCEPTANCE BY DSA. THE PROJECT INSPECTOR WILL VERIFY THAT ALL COMPONENTS AND EQUIPMENT HAVE BEEN ANCHORED IN ACCORDANCE WITH ABOVE REQUIREMENTS.

MEP DISTRIBUTION SYSTEM BRACING NOTE FOR
PIPING, DUCTWORK AND ELECTRICAL CONDUIT

APPLICABLE CODE: 2022 CBC PER IR 16-13

PIPING, DUCTWORK AND ELECTRICAL DISTRIBUTION SYSTEMS SHALL BE BRACED TO COMPLY WITH THE FORCES AND DISPLACEMENTS PRESCRIBED IN ASCE 7 SECTION 13.3 AS DEFINED IN ASCE 7 SECTIONS 13.6.5, 13.6.6, 13.6.7, AND 13.6.8; AND 2022 CBC SECTIONS 1617A.1.24, 1617A.1.25, AND 1617A.1.26.

THE METHOD OF SHOWING BRACING AND ATTACHMENTS TO THE STRUCTURE FOR THE IDENTIFIED DISTRIBUTION SYSTEM ARE AS NOTED BELOW. THE MEP DESIGN PROFESSIONAL ENGINEER RESPONSIBLE FOR CONTENT ON THESE SHEETS HAS VERIFIED THAT THE DESIGN METHODS IDENTIFIED BELKOW ARE IN ACCORDANCE WITH DSA 1R 16-13.

MECHANICAL PIPING (MP), MECHANICAL DUCTS (MD), PLUMBING PIPING (PP), ELECTRICAL DISTRIBUTION SYSTEMS (E):

MP ☐ MD ☐ PP ☐ E ☒ OPTION 1: PROJECT SPECIFIC DESIGN

MP ☐ MD ☐ PP ☐ E ☐ OPTION 2: DESIGN BASED ON OSHPD OPM, WITHIN PROJECT SUBMITTAL.

MP ☐ MD ☐ PP ☐ E ☐ OPTION 2: DESIGN BASED ON OSHPD OPM, DEFERRED SUBMITTAL.






ELECTRICAL SYMBOL LIST

NOTE: DASHED SYMBOLS ON PLANS DENOTE EXISTING DEVICES


- 20A, 125V, 3W GROUNDING TYPE DUPLEX RECEPTACLE, +18" U.O.N.
- 20A, 125V DUPLEX GFI RECEPTACLE, +18" U.O.N.
- JUNCTION BOX, CEILING OR WALL MOUNTED - SIZED PER CODE
- DISCONNECT SWITCH - FUSED AS REQUIRED, WEATHERPROOF FOR OUTDOORS, SIZED PER MANUFACTURER'S REQUIREMENTS
- MOTOR CONNECTION
- THERMAL OVERLOAD SWITCH
- MANUAL MOTOR STARTING SWITCH, HORSE POWER RATED WITH OVERLOADS
- EXISTING CONDUIT
- BRANCH CIRCUIT CONDUIT CONCEALED IN WALL OR CEILING
- BRANCH CIRCUIT CONDUIT CONCEALED UNDER FLOOR OR UNDERGROUND
- HOMERUN TO PANELBOARD OR OTHER TERMINATION POINT
- STUB CONDUIT TO ACCESSIBLE SPACE
- CONDUIT UP
- CONDUIT DOWN

- EXISTING
- NEW
- COPPER
- GROUND FAULT INTERRUPTER
- GROUND FAULT PROTECTION
- EMPTY CONDUIT WITH PULL CORD
- PULL BOX
- SEE ARCHITECTURAL DRAWINGS
- SIGNAL TERMINAL CABINET
- WEATHERPROOF
- UNDERGROUND
- UNLESS OTHERWISE NOTED
- VERIFY IN FIELD
- NUMBERED ELECTRICAL NOTE
- MECHANICAL TAG - LETTER DENOTES TYPE, NUMBER DENOTES EQUIPMENT NUMBER

ANY BRANCH CIRCUIT CONDUIT SHALL BE MINIMUM 3/4" C - 2#12, 1#12 GREEN GROUND UNLESS OTHERWISE NOTED. FOR A GREATER NUMBER OF #12 WIRES: (= 3/4" C - 3#12, 1#12G) ETC. FOR WIRE SIZES OTHER THAN #12: (= 3#8, 1#12G), (GROUND SIZED PER CEC, IN CODE SIZE CONDUIT) ETC.

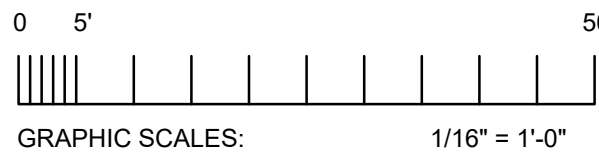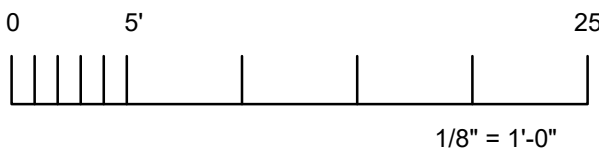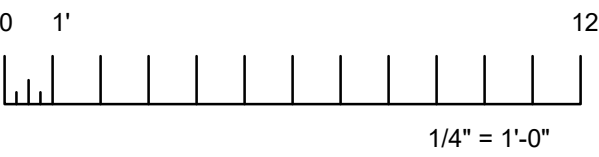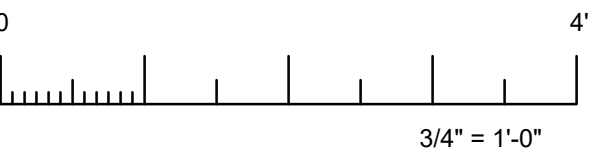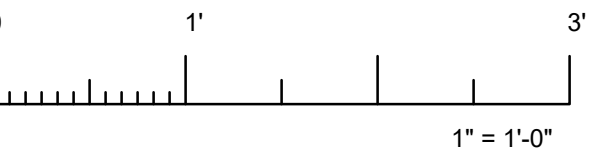


IF THIS SHEET IS NOT 30"x42". IT IS A REDUCED PRINT; SCALE ACCORDINGLY

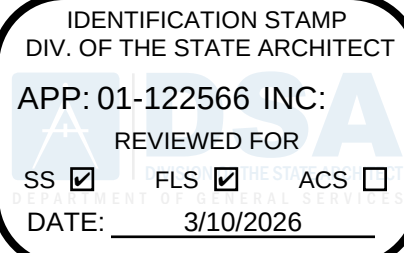

<div><div><div>#</div></div>Revisions</div>			
Delta	Date	Revisions	By

KEY PLAN

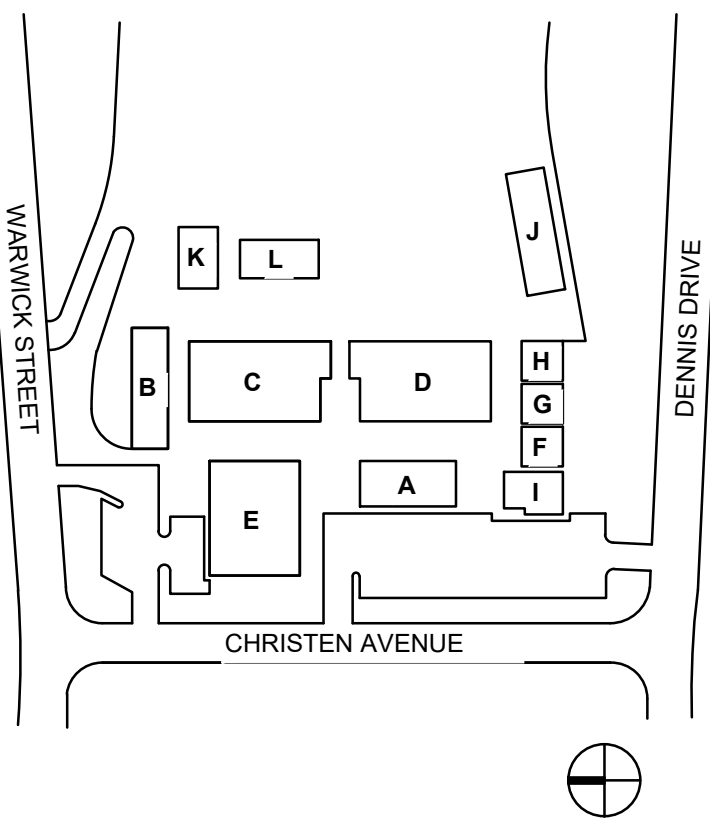

WORM

Electrical Consultants Incorporated
3397 Mt. Diablo Blvd., Suite C
Lafayette, CA 94549
Tel: 925-385-0549
25-004

This document is the property of the Owner and is not to be used without their written permission.



HIBSER YAMAUCHI
Architects, Inc.
300 - 27th Street
Oakland, CA 94612
510.446.2222 tel | 510.446.2211 fax
HY ARCHITECTS JOB NUMBER XXXX

Facility
SKYLINE ELEMENTARY SCHOOL
55 CHRISTEN AVE, DALY CITY, CA 94015

Project
HVAC REPLACEMENT

Sheet Title
ELECTRICAL PANEL SCHEDULES

Client Project Number: XXXX

Scale: AS NOTED

Drawn By: DAM

Checked By: TLK

Issue Date: 09/15/25

Revit Version: 2023

E0.02

EXISTING PANEL NA

NURSE A4

DESCRIPTION	LOAD (KVA)				CB	CKT	SN	CB	LOAD (KVA)				DESCRIPTION
	LTG.	REC.	RES.	MOT.					LTG.	REC.	RES.	MOT.	
EXH FAN - WOMENS TOILET					201	1	*	2	201				FURNACE
EXH FAN - MENS TOILET					201	3	*	4	201				EXT LIGHTS
SPARE					201	5	*	6	201				SPARE
TEACHERS LOUNGE RECEPT					201	7	*	8	201				HVAC GLOBAL CONTROLLER
TEACHERS LOUNGE CEILING JBOX					201	9	*	10	201				SPARE
SPARE					201	11	*	12	201				SPARE
SPARE					201	13	*	14	201				SPARE
SPARE					201	15	*	16	201				SPARE
SPARE					201	17	*	18	201				SPARE
SPARE					201	19	*	20	201				SPARE
SPARE					201	21	*	22	201				SPARE
SPARE					201	23	*	24	201				SPARE
SPARE					201	25	*	26	201				SPARE
SPARE					201	27	*	28	201				SPARE
SPARE					201	29	*	30					
CU-A1				6.40	50/2	31	*	32	20/3				SPARE
SPACE						33	*	34					
ROOF RECEPT						35	*	36	20/1				SPARE
SPARE						201	37	*	38				
SPARE						201	39	*	40	100/3			(E) PANEL 'A'
SPARE						15/1	41	*	42				
TOTAL												1.70	
VOLTS: 120/208V,3ø,4W	MTG: SURFACE												
BUS: 225 AMP	TYPE: A-SERIES	CONNECTED KVA: 8.10											
MAIN: 225 AMP MB	KAIC: (E) 10	CONNECTED AMPS: 22.50											

EXISTING PANEL NE

KITCHEN

DESCRIPTION	LOAD (KVA)				CB	CKT	SN	CB	LOAD (KVA)				DESCRIPTION
	LTG.	REC.	RES.	MOT.					LTG.	REC.	RES.	MOT.	
EXHAUST FAN - TOILETS					20/1	1	*	2	20/1				WHEELCHAIR LIFT
SPARE					20/1	3	*	4	20/1				FURNACE - ESL
SPARE					20/1	5	*	6	20/1			1.70	FURNACE - MP ROOM
EXHAUST FAN - OFFICE					20/1	7	*	8	20/1				SPARE
ROLL IN REFRIGERATOR					20/1	9	*	10	20/1				SPARE
ROLL IN REFRIGERATOR					20/1	11	*	12	20/1				SPARE
SPARE					20/1	13	*	14	20/1				SPARE
SPARE					20/1	15	*	16	20/1				SPARE
SPARE					20/1	17	*	18	20/1				SPARE
SPARE					20/1	19	*	20	20/1				SPARE
SPARE					20/1	21	*	22	30/2			3.90	CU-E3
SPARE					20/1	23	*	24					
SPARE					20/1	25	*	26	50/2				6.40
SPARE					20/1	27	*	28	50/2				CU-E2
SPARE					20/1	29	*	30					SPACE
FURNACE - MP ROOM				1.70	20/1	31	*	32	50/2				6.40
EXT. LIGHT					20/1	33	*	34					SPACE
SPARE					15/3	37	*	38	20/1				SPACE
SPACE						39	*	40					SPACE
SPACE						41	*	42					SPACE
TOTAL											3.40	16.70	
VOLTS: 120/208V,3ø,4W	MTG: RECESSED												
BUS: 400 AMP	TYPE: GE A-SERIES	CONNECTED KVA: 21.80											
MAIN: 400 AMP MB	KAIC: (E)	CONNECTED AMPS: 60.56											

EXISTING PANEL NB

STORAGE B8

DESCRIPTION	LOAD (KVA)				CB	CKT	SN	CB	LOAD (KVA)				DESCRIPTION
	LTG.	REC.	RES.	MOT.					LTG.	REC.	RES.	MOT.	
RCPT - COMP RM 1					20/1	1	*	2	20/1				RCPT - COMP RM 2
RCPT - COMP RM 1					20/1	3	*	4	20/1				RCPT - COMP RM 2
RCPT - PRINTER RM 1					20/1	5	*	6	20/1				RCPT - PRINTER RM 2
RCPT - TEACHR STA RM 1					20/1	7	*	8	20/1				RCPT - TEACHR STA RM 2
EXT LIGHTS - BLDG B					20/1	9	*	10	20/1				IDF
SPARE					20/1	11	*	12	20/1				SPARE
SPARE					20/1	13	*	14	20/1				SPARE
SPARE					20/1	15	*	16	20/1				SPARE
SPARE					20/1	17	*	18	20/1				SPARE
CU-B1				3.90	30/2	19	*	20	20/1				SPARE
						21	*	22	20/1				SPARE
CU-B2				3.90	30/2	23	*	24	20/1				SPARE
						25	*	26	20/1				SPARE
CU-C1				3.90	30/2	27	*	28	20/1				SPARE
						29	*	30	20/1				SPARE
CU-C2				3.90	30/2	31	*	32	20/1				SPARE
						33	*	34	20/1				SPARE
CU-C5				3.90	30/2	35	*	36	20/1				SPACE
						37	*	38					
CU-C5				3.90	30/2	39	*	40	100/3				(E) PANEL 'C'
						41	*	42					
TOTAL												23.40	
VOLTS: 120/208V,3ø,4W	MTG: SURFACE												
BUS: 225 AMP	TYPE: A-SERIES	CONNECTED KVA: 23.40											
MAIN: 225 AMP MB	KAIC: (E) 10	CONNECTED AMPS: 65.00											

EXISTING PANEL NC

CUSTODIAN C8

DESCRIPTION	LOAD (KVA)				CB	CKT	SN	CB	LOAD (KVA)				DESCRIPTION
	LTG.	REC.	RES.	MOT.					LTG.	REC.	RES.	MOT.	
RCPT - COMP RM 8					20/1	1	*	2	20/1				RCPT - COMP RM 7
RCPT - COMP RM 8					20/1	3	*	4	20/1				RCPT - COMP RM 7
RCPT - PRINTER RM 8					20/1	5	*	6	20/1				RCPT - PRINTER RM 7
RCPT - TEACHR STA RM 8					20/1	7	*	8	20/1				RCPT - TEACHR STA RM 7
RCPT - COMP RM 5					20/1	9	*	10	20/1				RCPT - COMP RM 6
RCPT - COMP RM 5					20/1	11	*	12	20/1				RCPT - COMP RM 6
RCPT - PRINTER RM 5					20/1	13	*	14	20/1				RCPT - PRINTER RM 6
RCPT - TEACHR STA RM 5					20/1	15	*	16	20/1				RCPT - TEACHR STA RM 6
RCPT - COMP RM 4					20/1	17	*	18	20/1				RCPT - COMP RM 3
RCPT - COMP RM 4					20/1	19	*	20	20/1				RCPT - COMP RM 3
RCPT - PRINTER RM 4					20/1	21	*	22	20/1				RCPT - PRINTER RM 3
RCPT - TEACHR STA RM 4					20/1	23	*	24	20/1				RCPT - TEACHR STA RM 3
FURNACE - RM 6				1.70	20/1	25	*	26					
FURNACE - RM 3				1.70	20/1	27	*	28	30/2			3.90	CU-D6
FURNACE - RM 8				1.70	20/1	29	*	30	30/2				CU-D1
FURNACE - RM 5				1.70	20/1	31	*	32					IDF
FURNACE - RM 4				1.70	20/1	33	*	34	20/1				SPARE
FURNACE - RM 7				1.70	20/1	35	*	36	20/1				RECEPTACLE ROOF
EXT LIGHTS					20/1	37	*	38	20/1				SPARE
(E) PANEL D (225 AMP)						39	*	40	20/1				(E) PANEL D (225 AMP)
(E) PANEL D (225 AMP)						41	*	42					
TOTAL											10.20		7.80
VOLTS: 120/208V,3ø,4W	MTG: SURFACE												
BUS: 400 AMP	TYPE: A-SERIES	CONNECTED KVA: 18.00											
MAIN: 400 AMP MB	KAIC: (E) 10	CONNECTED AMPS: 50.00											

EXISTING PANEL ND

STORAGE D8

DESCRIPTION	LOAD (KVA)				CB	CKT	SN	CB	LOAD (KVA)
-------------	------------	--	--	--	----	-----	----	----	------------



IF THIS SHEET IS NOT 30"x42". IT IS A REDUCED PRINT; SCALE ACCORDINGLY

IDENTIFICATION STAMP
DIV. OF THE STATE ARCHITECT
APP: 01-122566 INC.
REVIEWED FOR
SS ☒ FLS ☒ ACS ☐
DATE: 3/10/2026

EXISTING PANEL B-1 - SECTION 1													KITCHEN			
DESCRIPTION	LOAD (KVA)				CB	CKT	SN	CKT	CB	LOAD (KVA)				DESCRIPTION		
	LTG.	REC.	RES.	MOT.						LTG.	REC.	RES.	MOT.			
LIGHTS - MULTI-USE ROOM					201	1	*	2	201					LIGHTS - MULTI-USE ROOM		
LIGHTS - MULTI-USE ROOM					201	3	*	4	201					LIGHTS - MULTI-USE ROOM		
LIGHTS - MULTI-USE ROOM					201	5	*	6	201					LIGHTS - MULTI-USE ROOM		
LIGHTS - KITCHEN					201	7	*	8	201					LIGHTS - TEACHERS DINING & HOOD		
LIGHTS - DISHWASHING, JANITOR, BATH					201	9	*	10	201					LIGHTS - LOBBY, CUSTODIAN, BATHROOM		
LIGHTS - MECH. LARGE STORAGE					201	11	*	12	201					LIGHTS - STAGE, OFFICE		
LIGHTS - OUTSIDE FLOOD - RELAY 'C'					201	13	*	14	201					LIGHTS - OUTSIDE FLOOD - RELAY 'C'		
LIGHTS - OUTSIDE FLOOD - RELAY 'D'					201	15	*	16	201					LIGHTS - EXIT, EMERGENCY BATTERY, CUST		
LIGHTS - OUTSIDE RECESS					201	17	*	18	201							
RELAY CIRCUIT FOR MULTI-USE LIGHT					201	19	*	20	201					PLUGS - OFFICE, STAGE, LARGE STORAGE		
PLUGS - MULTI-USE WALL & FLOOR					201	21	*	22	201					PLUG - P.A. CONTROL PANEL		
PLUGS - MULTI-USE ROOM					201	23	*	24	201					PLUGS - MULTI-USE ROOM BY STAGE		
PLUGS - MULTI-USE, OUTSIDE CORR					201	25	*	26	201					PLUGS - KITCHEN		
PLUGS - DISHWASHING, STORAGE, PANEL					201	27	*	28	201					PLUGS - KITCHEN		
PLUGS - JANITOR, DRESSING, BATH, MECH					201	29	*	30	201					PLUGS - KITCHEN - CONVEN OVENS		
PLUG - KITCHEN COOLER					201	31	*	32	201							
PLUGS - KITCHEN COUNTER, OUTSIDE					201	33	*	34	201					PLUGS - TEACHERS DINING		
FAN - ROOF FAN E-5 - MECH PANEL					201	35	*	36	201					PLUGS - MEN & WOMEN BATH, CUST		
FAN - ROOF FAN E-4 - MECH PANEL					201	37	*	38	201					PLUG - LOBBY		
FAN - ROOF FAN E-7 - DISHWASHING					201	39	*	40	201					FAN - ROOF FAN E-8, MECH PANEL		
WATER HEATER CIRCULATING PUMP					201	41	*	42	201				1.70	FURNACE - S-2, MECH ROOM		
TOTAL													1.70			
VOLTS: 120/208V,3ø,4W	MTG: RECESSED								SECTION 1 KVA: 1.70							
BUS: 225 AMP	TYPE: ITE NLAB								CONNECTED AMPS: 4.72							
MAIN: 225 AMP	KAIC: (E)															

EXISTING PANEL E																	
DESCRIPTION	LOAD (KVA)				CB	CKT	SN	CKT	CB	LOAD (KVA)				DESCRIPTION			
	LTG.	REC.	RES.	MOT.						LTG.	REC.	RES.	MOT.				
LIGHTS - CLASSROOM C12					201	1	*	2	201					LIGHTS - CLASSROOM C11			
LIGHTS - CLASSROOM C13					201	3	*	4	201					LIGHTS - INSIDE HALLWAY			
LIGHTS - BATHROOM, STORAGE					201	5	*	6	201					LIGHTS - CLASSROOM C14			
LIGHTS - CLASSROOM C7					201	7	*	8	201					LIGHTS - INSIDE PATIO			
LIGHTS - CLASSROOM C6					201	9	*	10	201					SPARE			
SPARE					201	11	*	12	201					SPARE			
PLUGS - CLASSROOM C7/C9					201	13	*	14	201					PLUGS - CLASSROOM C16			
PLUGS - OUTSIDE, CLASSROOM C12					201	15	*	16	201					PLUGS - CLASSROOM C11, OUTSIDE			
PLUGS - CLASSROOM C13					201	17	*	18	201					PLUGS - CLASSROOM C14, HALL			
PLUGS - BATHROOM, STOR					201	19	*	20	201					SPARE			
CU-D2					30/2	21	*	22	201					SPARE			
					30/2	23	*	24	201					SPARE			
CU-D3					30/2	25	*	26	40/2					KILN			
					30/2	27	*	28						SPARE			
					30/2	29	*	30	201					SPARE			
					31	*	32	201						SPARE			
SPARE					201	33	*	34	201					SPARE			
SPACE						35	*	36	201					SPARE			
TOTAL					7.80												
VOLTGS: 120/208V,3ø,4W MTG: RECESSED																	
BUS: 225 AMP TYPE: ITE NLAB																	
MAIN: 225 AMP MB KAIC: (E)																	
CONNECTED KVA: 7.80																	
CONNECTED AMPS: 21.67																	

SHEET NOTES

- ① CONNECT NEW UNIT TO EXISTING CIRCUIT.

EXISTING PANEL B-2 - SECTION 2													KITCHEN			
DESCRIPTION	LOAD (KVA)				CB	CKT	SN	CKT	CB	LOAD (KVA)				DESCRIPTION		
	LTG.	REC.	RES.	MOT.						LTG.	REC.	RES.	MOT.			
FURNACE CONTROLS					201	43	*	44	201					MECH CONTROL PANEL - COIL CIRCUIT		
FLOW ALARM					201	45	*	46	201					FURNACE CONTROLS		
PLUG - KITCHEN FLOOR					201	47	*	48	201							
PLUG - KITCHEN FLOOR					201	49	*	50	201							
PLUG - KITCHEN FLOOR					201	51	*	52	201					PLUG - 220 VOLT KITCHEN FLOOR		
					201	53	*	54	201					PLUG - 220 VOLT KITCHEN FLOOR		
						55	*	56								
FAN - E-6, KITCHEN HOOD					203		*		203					DISHWASHER MOTOR		
						57	*	58								
DISHWASHER - HEATING ELEMENT					203		*		203					GARBAGE DISPOSAL - KITCHEN		
						59	*	60								
GARAGE DISPOSAL - KITCHEN					203		*		203					FURNACE - S-1, MECH ROOM		
						61	*	62						SPACE		
					203		*							SPACE		
						63	*	64						SPACE		
SPACE						65	*	66						SPACE		
SPACE						67	*	68						SPACE		
TOTAL																
VOLTS: 120/208V,3ø,4W	MTG: SURFACE				SECTION 1 KVA: 1.70				TOTAL KVA: 1.70							
BUS: 400 AMP	TYPE: NOOD				CONNECTED AMPS: 4.72											
MAIN: 300 AMP MB	KAIC: 10															

EXISTING PANEL C													STORAGE B8			
DESCRIPTION	LOAD (KVA)				CB	CKT	SN	CKT	CB	LOAD (KVA)				DESCRIPTION		
	LTG.	REC.	RES.	MOT.						LTG.	REC.	RES.	MOT.			
CLASSROOM 2 LIGHTS OUTER					201	1	*	2	201							
					201	3	*	4	201							
CLASSROOM 2 LIGHTS CENTER					201	5	*	6	201					ROOF FLOODS RELAY B		
					201	7	*	8	201							
					201	9	*	10	201					BRACKET LITES RELAY A		
					201	11	*	12	201							
					201	13	*	14	201							
					201	15	*	16	201							
FURNACE CLASSROOM 1				1.70	201	17	*	18	201					ROOF FAN		
FURNACE CLASSROOM 2				1.70	201	19	*	20	201					HEAT CONTROL		
					201	21	*	22	201							
					201	23	*	24	201							
SPACE						25	*	26						SPACE		
SPACE						27	*	28						SPACE		
SPACE						29	*	30						SPACE		
TOTAL				3.40												
VOLTS: 120/208V,3ø,4W	MTG: RECESSED								CONNECTED KVA: 3.40							
BUS: 100 AMPS	TYPE: ITE NLAB								CONNECTED AMPS: 9.44							
MAIN: 100 AMPS	KAIC: (E)															



IF THIS SHEET IS NOT 30"x42". IT IS A
REDUCED PRINT; SCALE ACCORDINGLY

IDENTIFICATION STAMP
DIV. OF THE STATE ARCHITECT

APP: 01-122566 INC.

REVIEWED FOR


SS ☒ FLS ☒ ACS ☐

DATE: 3/10/2026



Revisions			
Delta	Date	Revisions	By

KEY PLAN

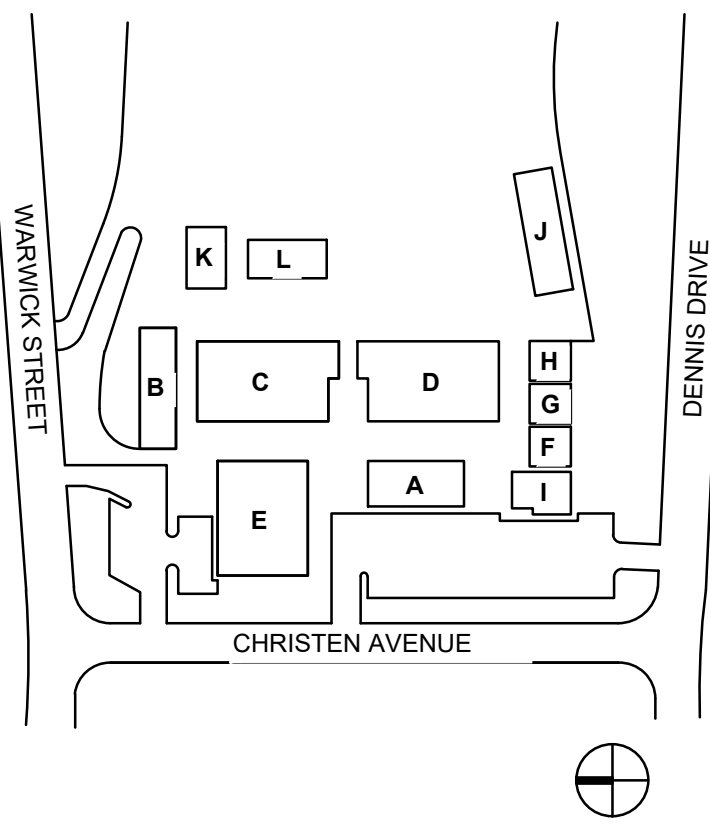

Electrical Consultants Incorporated
3397 Mt. Diablo Blvd., Suite C
Lafayette, CA 94549
Tel: 925-385-0549
25-004

This document is the property of the Owner and is not to be used without their written permission.



HY HIBSER YAMAUCHI
Architects, Inc.

300 - 27th Street
Oakland, CA 94612
510.446.2222 tel | 510.446.2211 fax

HY ARCHITECTS JOB NUMBER XXXX

Facility
SKYLINE ELEMENTARY SCHOOL
55 CHRISTEN AVE, DALY CITY, CA 94015

Project
HVAC REPLACEMENT


Sheet Title
ELECTRICAL POWER SITE PLAN

Client Project Number: XXXX







Scale: AS NOTED
Drawn By: DAM
Checked By: TLK
Issue Date: 09/15/25
Revit Version: 2023

E1.01

2/12/2026 6:15 AM c:\user\damon\wrm consulting\dropbox\cad\2025\25-004 skyline es hvac\25004 e1.01

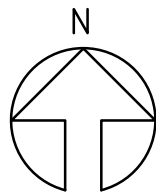

ELECTRICAL POWER SITE PLAN 1" = 20'-0" 1

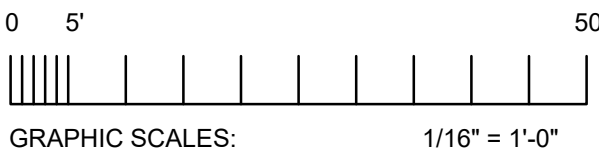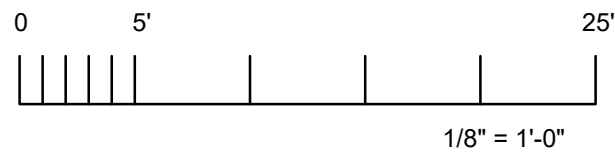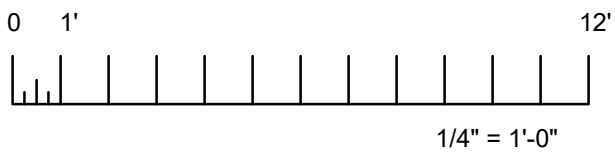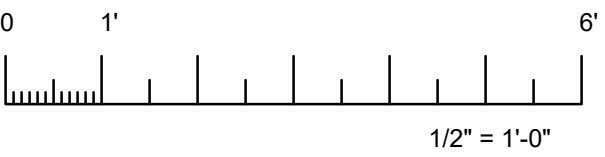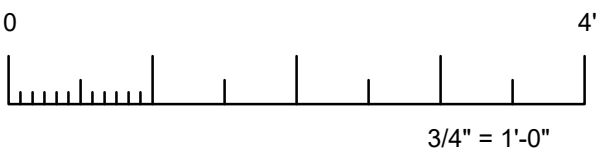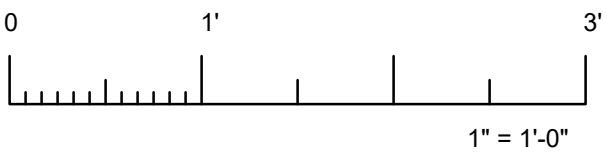


IF THIS SHEET IS NOT 30"x42". IT IS A
REDUCED PRINT; SCALE ACCORDINGLY

IDENTIFICATION STAMP
DIV. OF THE STATE ARCHITECT
APP: 01-122566 INC:
REVIEWED FOR
SS ☒ FLS ☒ ACS ☐
DATE: 3/10/2026



Revisions	Delta	Date	Revisions	By


KEY PLAN

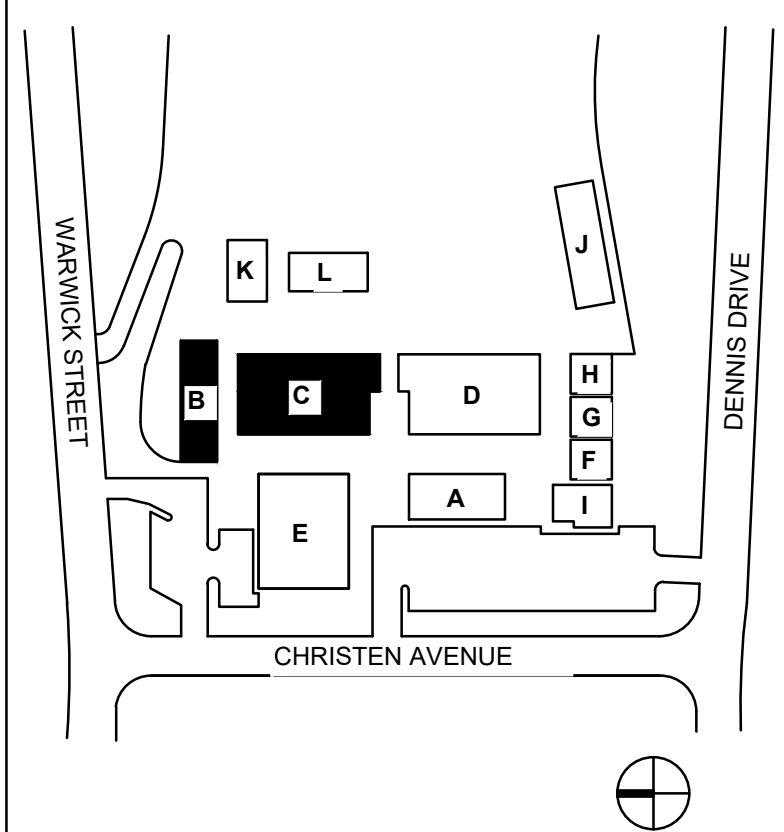

ELECTRICAL DEMOLITION POWER PLAN - BUILDINGS B & C

1/8" = 1'-0"

1

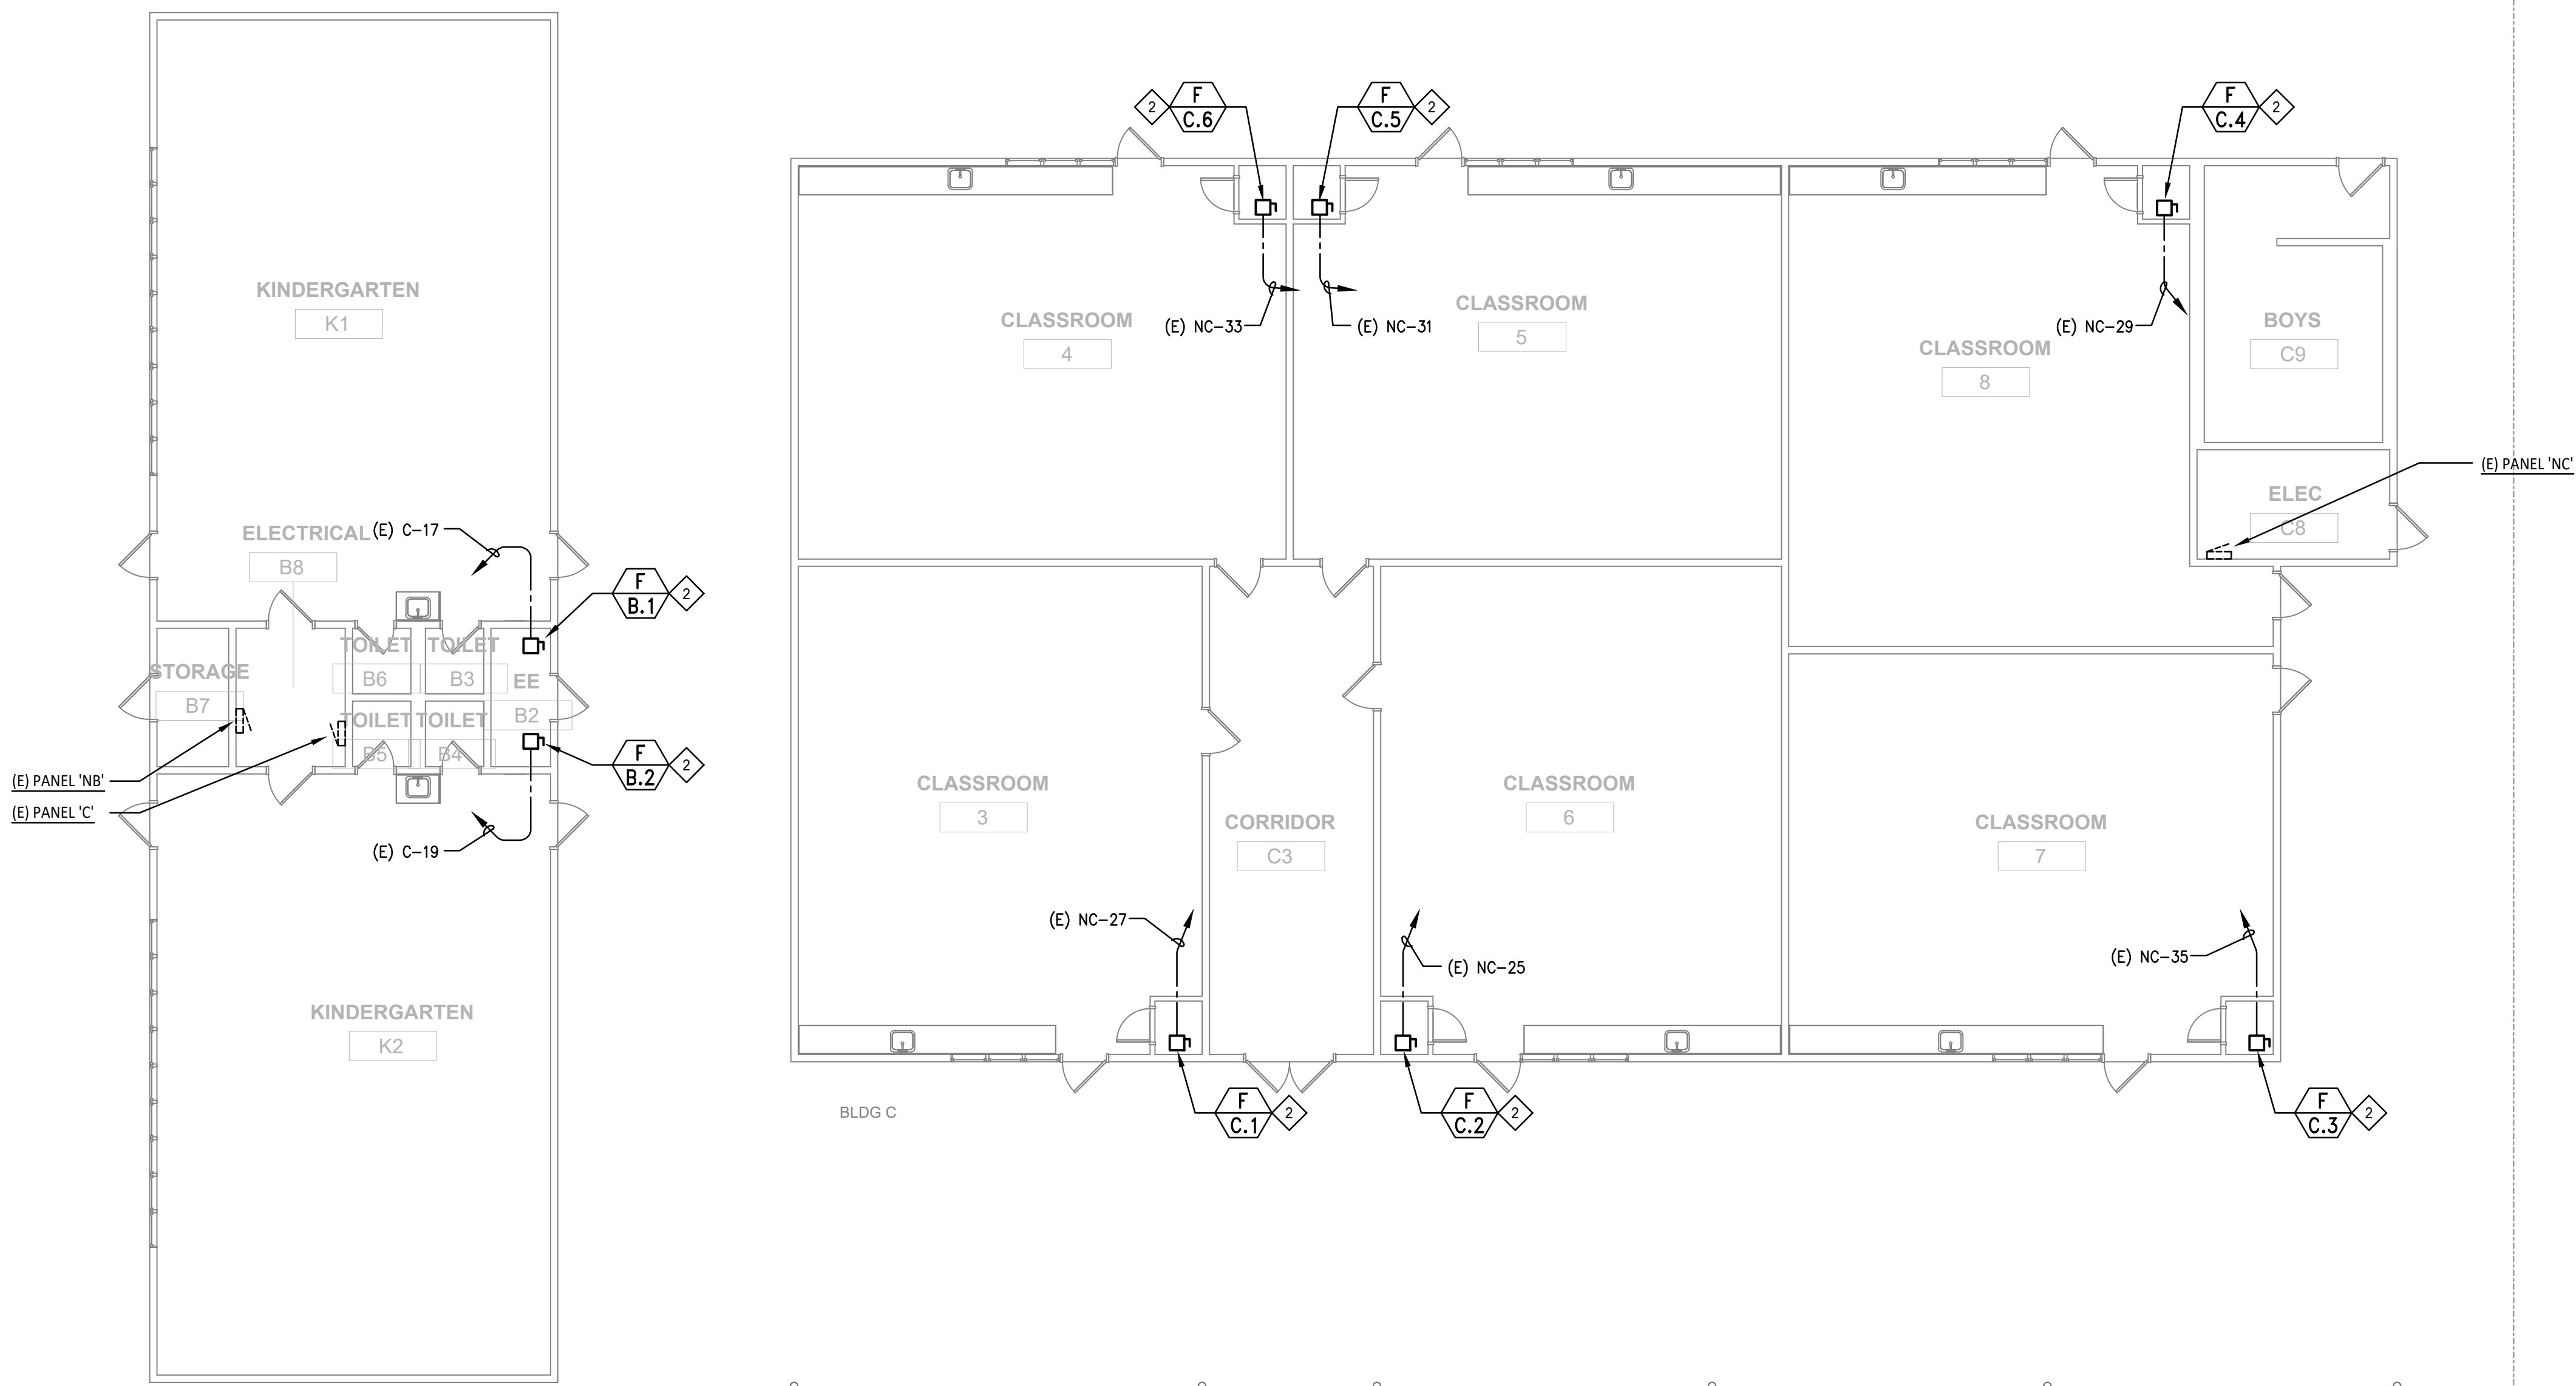

ELECTRICAL POWER PLAN - BUILDINGS B & C

1/8" = 1'-0"

2

GENERAL NOTES

- COORDINATE ALL CONNECTION REQUIREMENTS TO UNITS WITH MECHANICAL.
- EXISTING POWER TO EMS CONTROLLERS ARE TO REMAIN. RECONNECT TO NEW CONTROLLERS. COORDINATE LOCATIONS IN THE FIELD WITH MECHANICAL.

SHEET NOTES

- EXISTING DISCONNECT TO BE REPLACED WITH NEW FOR CONNECTION TO NEW UNIT. EXISTING CONDENSATE PUMP TO BE REPLACED AND RECONNECTED TO SAME CIRCUIT.
- RECONNECT EXISTING CONDUIT AND CONDUCTORS TO NEW FURNACE UNIT AND CONDENSATE PUMP. INTERCEPT AND EXTEND AS REQUIRED.

WORM

Electrical Consultants Incorporated
3397 Mt. Diablo Blvd., Suite C
Lafayette, CA 94549
Tel: 925-385-0549
25-004

This document is the property of the Owner and is not to be used without their written permission.



HY HIBSER YAMAUCHI
Architects, Inc.
300 - 27th Street
Oakland, CA 94612
510.446.2222 tel; 510.446.2211 fax

HY ARCHITECTS JOB NUMBER XXXX







Facility
SKYLINE ELEMENTARY SCHOOL
55 CHRISTEN AVE, DALY CITY, CA 94015

Project
HVAC REPLACEMENT

Sheet Title
ELECTRICAL POWER PLANS
BUILDINGS B AND C

Client Project Number: XXXX

Scale: AS NOTED	Sheet
Drawn By: DAM	E2.01
Checked By: TLK	
Issue Date: 09/15/25	
Revit Version: 2023	

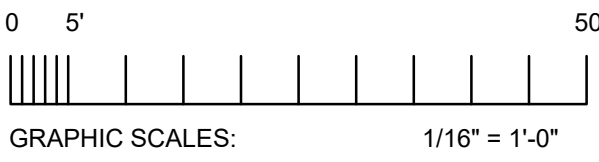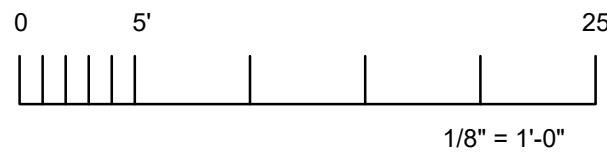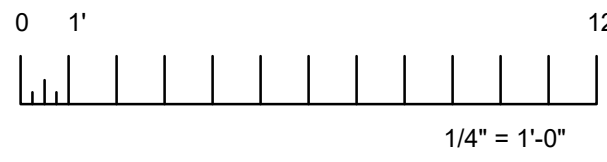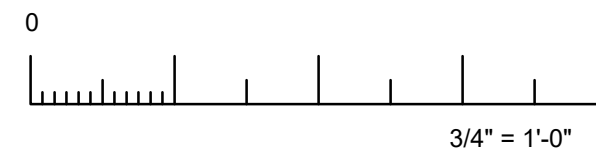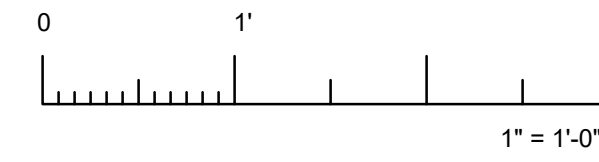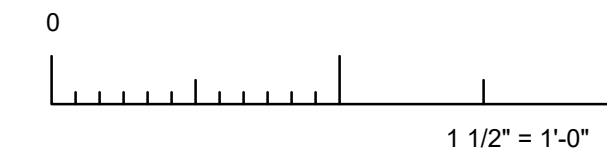


IF THIS SHEET IS NOT 30"x42". IT IS A
REDUCED PRINT; SCALE ACCORDINGLY

IDENTIFICATION STAMP
DIV. OF THE STATE ARCHITECT
APP: 01-122566 INC:
REVIEWED FOR
SS ☒ FLS ☒ ACS ☐
DATE: 3/10/2026



Revisions	Delta	Date	Revisions	By
-----------	-------	------	-----------	----

KEY PLAN

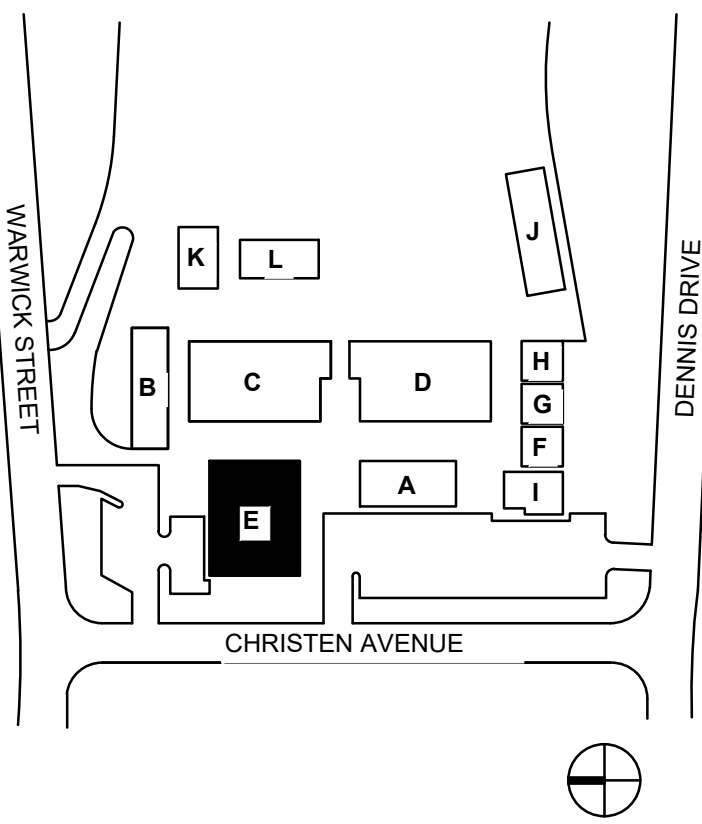

WORM

Electrical Consultants Incorporated
3397 Mt. Diablo Blvd., Suite C
Lafayette, CA 94549
Tel: 925-385-0549
25-004

This document is the property of the Owner and is not to be used without their written permission.



HY HIBSER YAMAUCHI
Architects, Inc.
300 - 27th Street
Oakland, CA 94612
510.446.2222 tel; 510.446.2211 fax

HY ARCHITECTS JOB NUMBER XXXX

Facility
SKYLINE ELEMENTARY SCHOOL
55 CHRISTEN AVE, DALY CITY, CA 94015

Project
HVAC REPLACEMENT

Sheet Title
ELECTRICAL POWER PLANS
BUILDING E

Client Project Number: XXXX

Scale: AS NOTED


Drawn By: DAM

Checked By: TLK

Issue Date: 09/15/25

Revit Version: 2023


E2.02

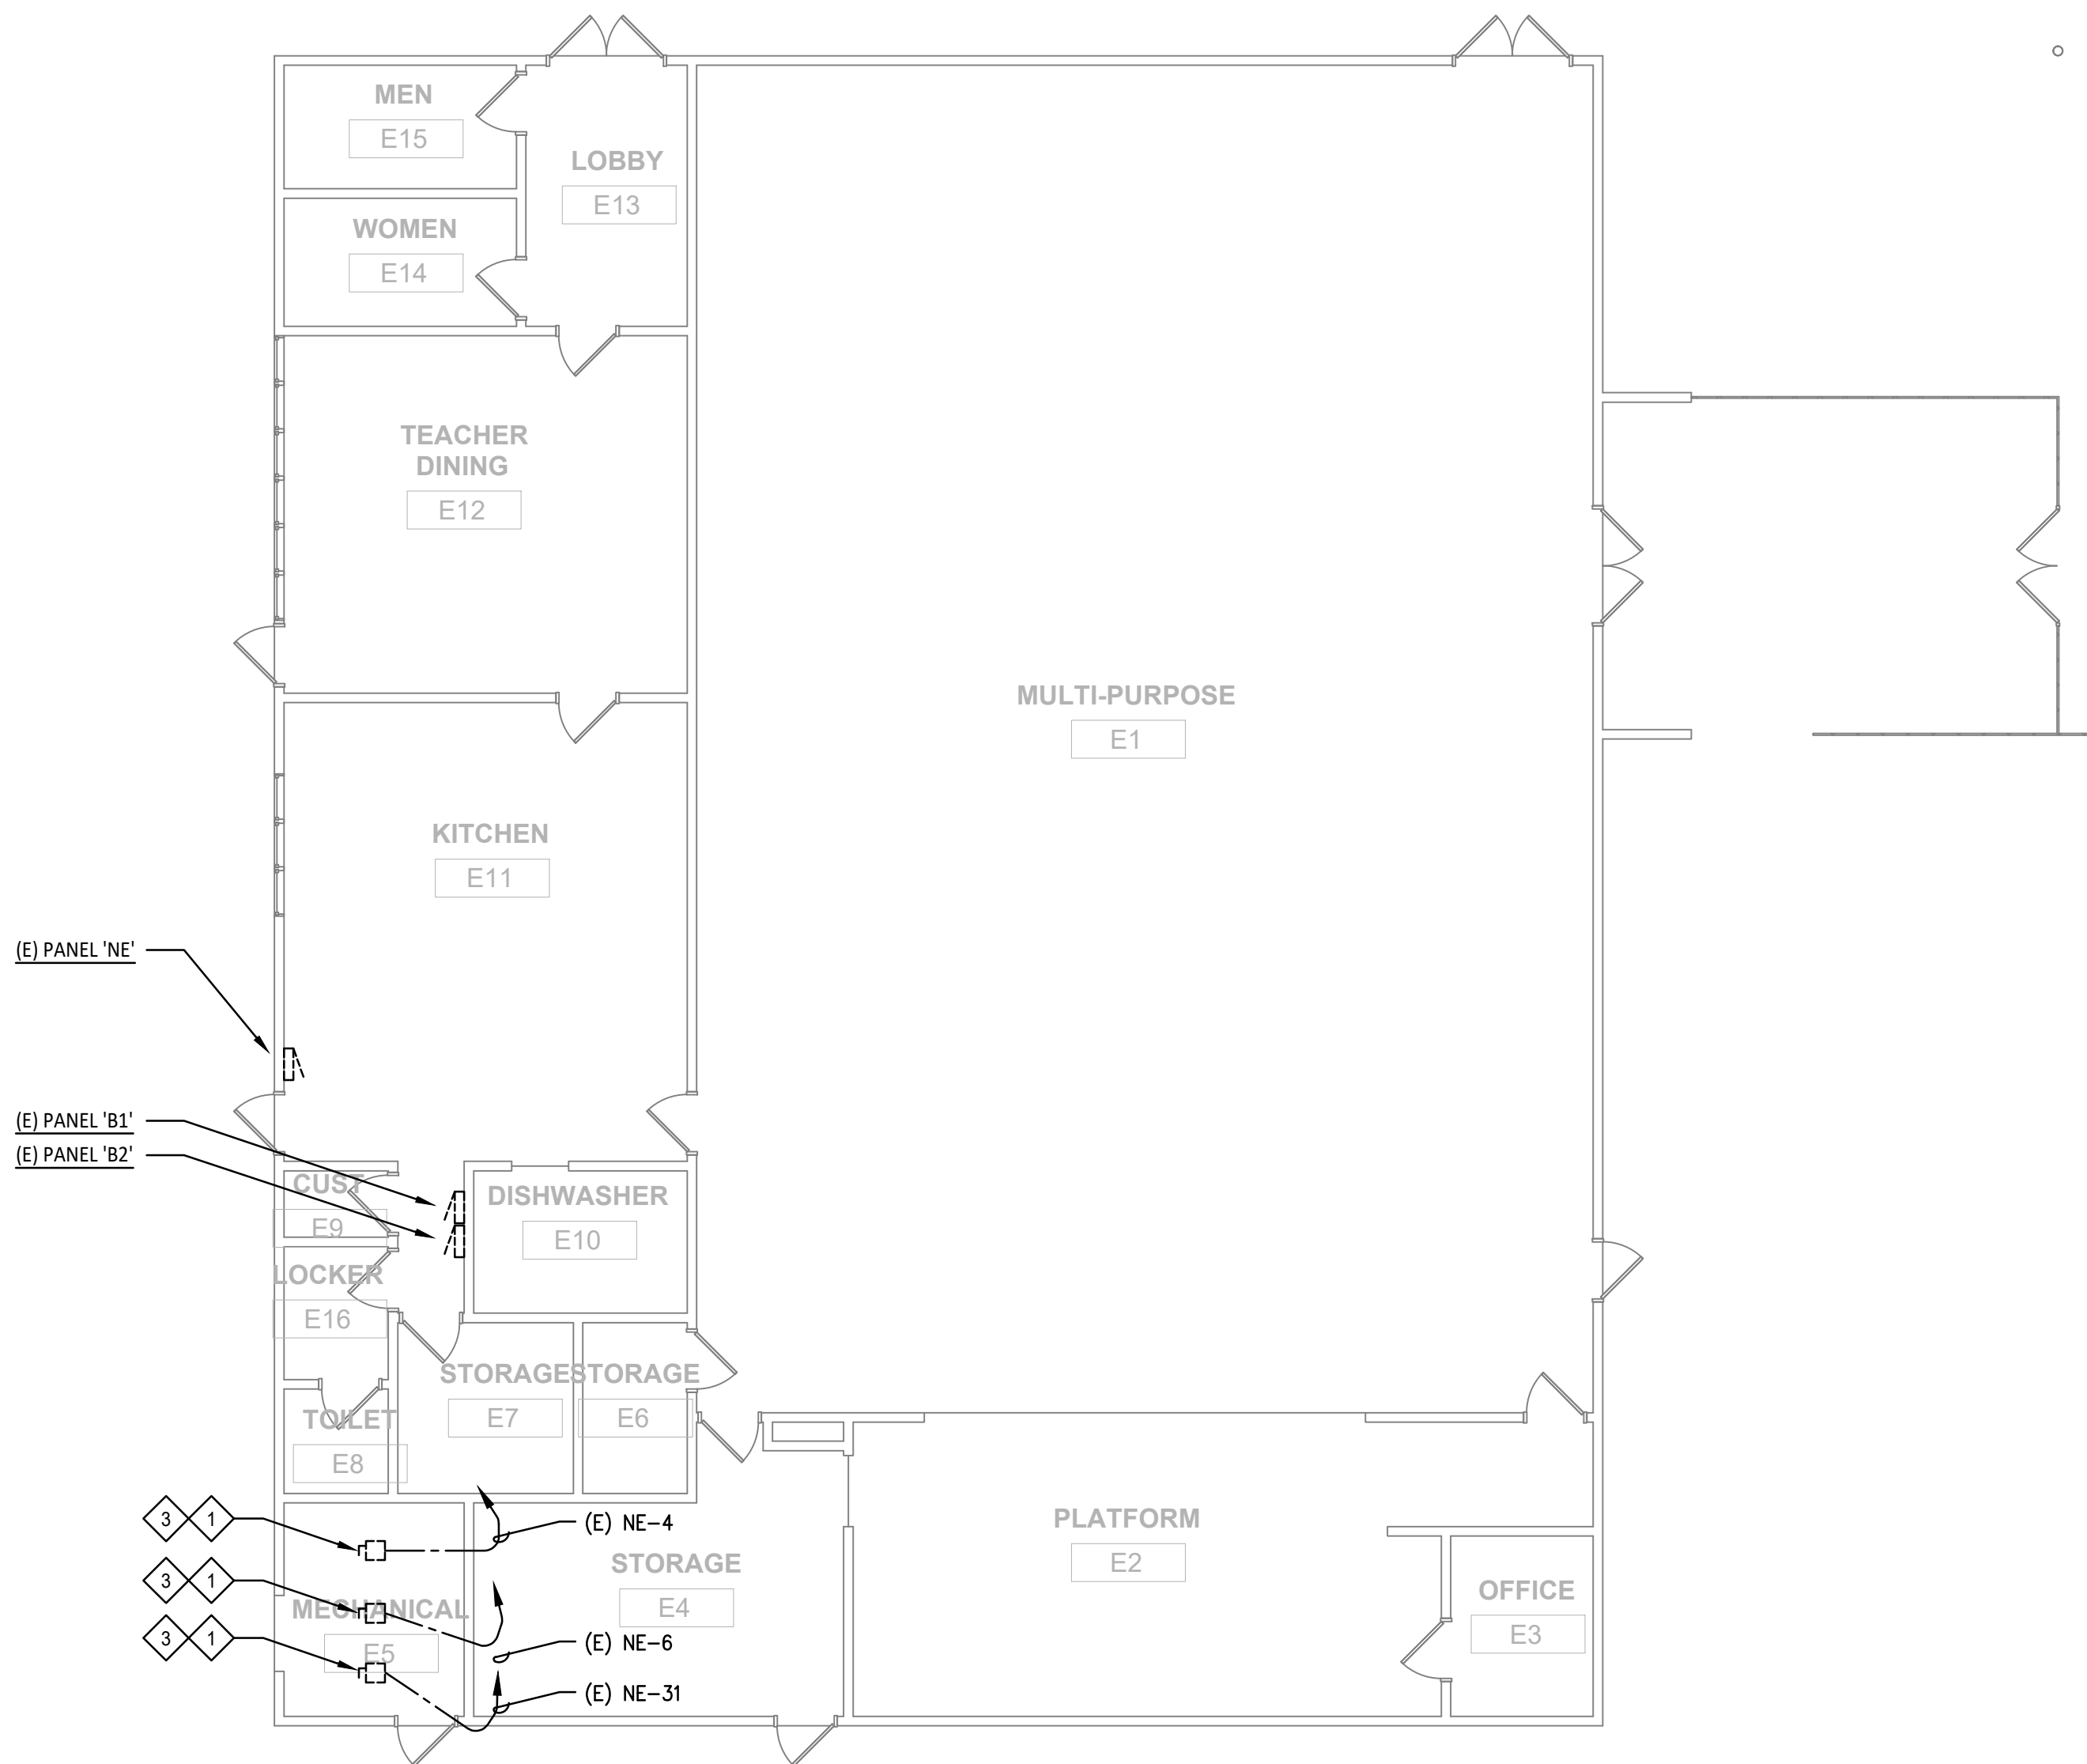

ELECTRICAL DEMOLITION POWER PLAN - BUILDING E

1/8" = 1'-0"

1

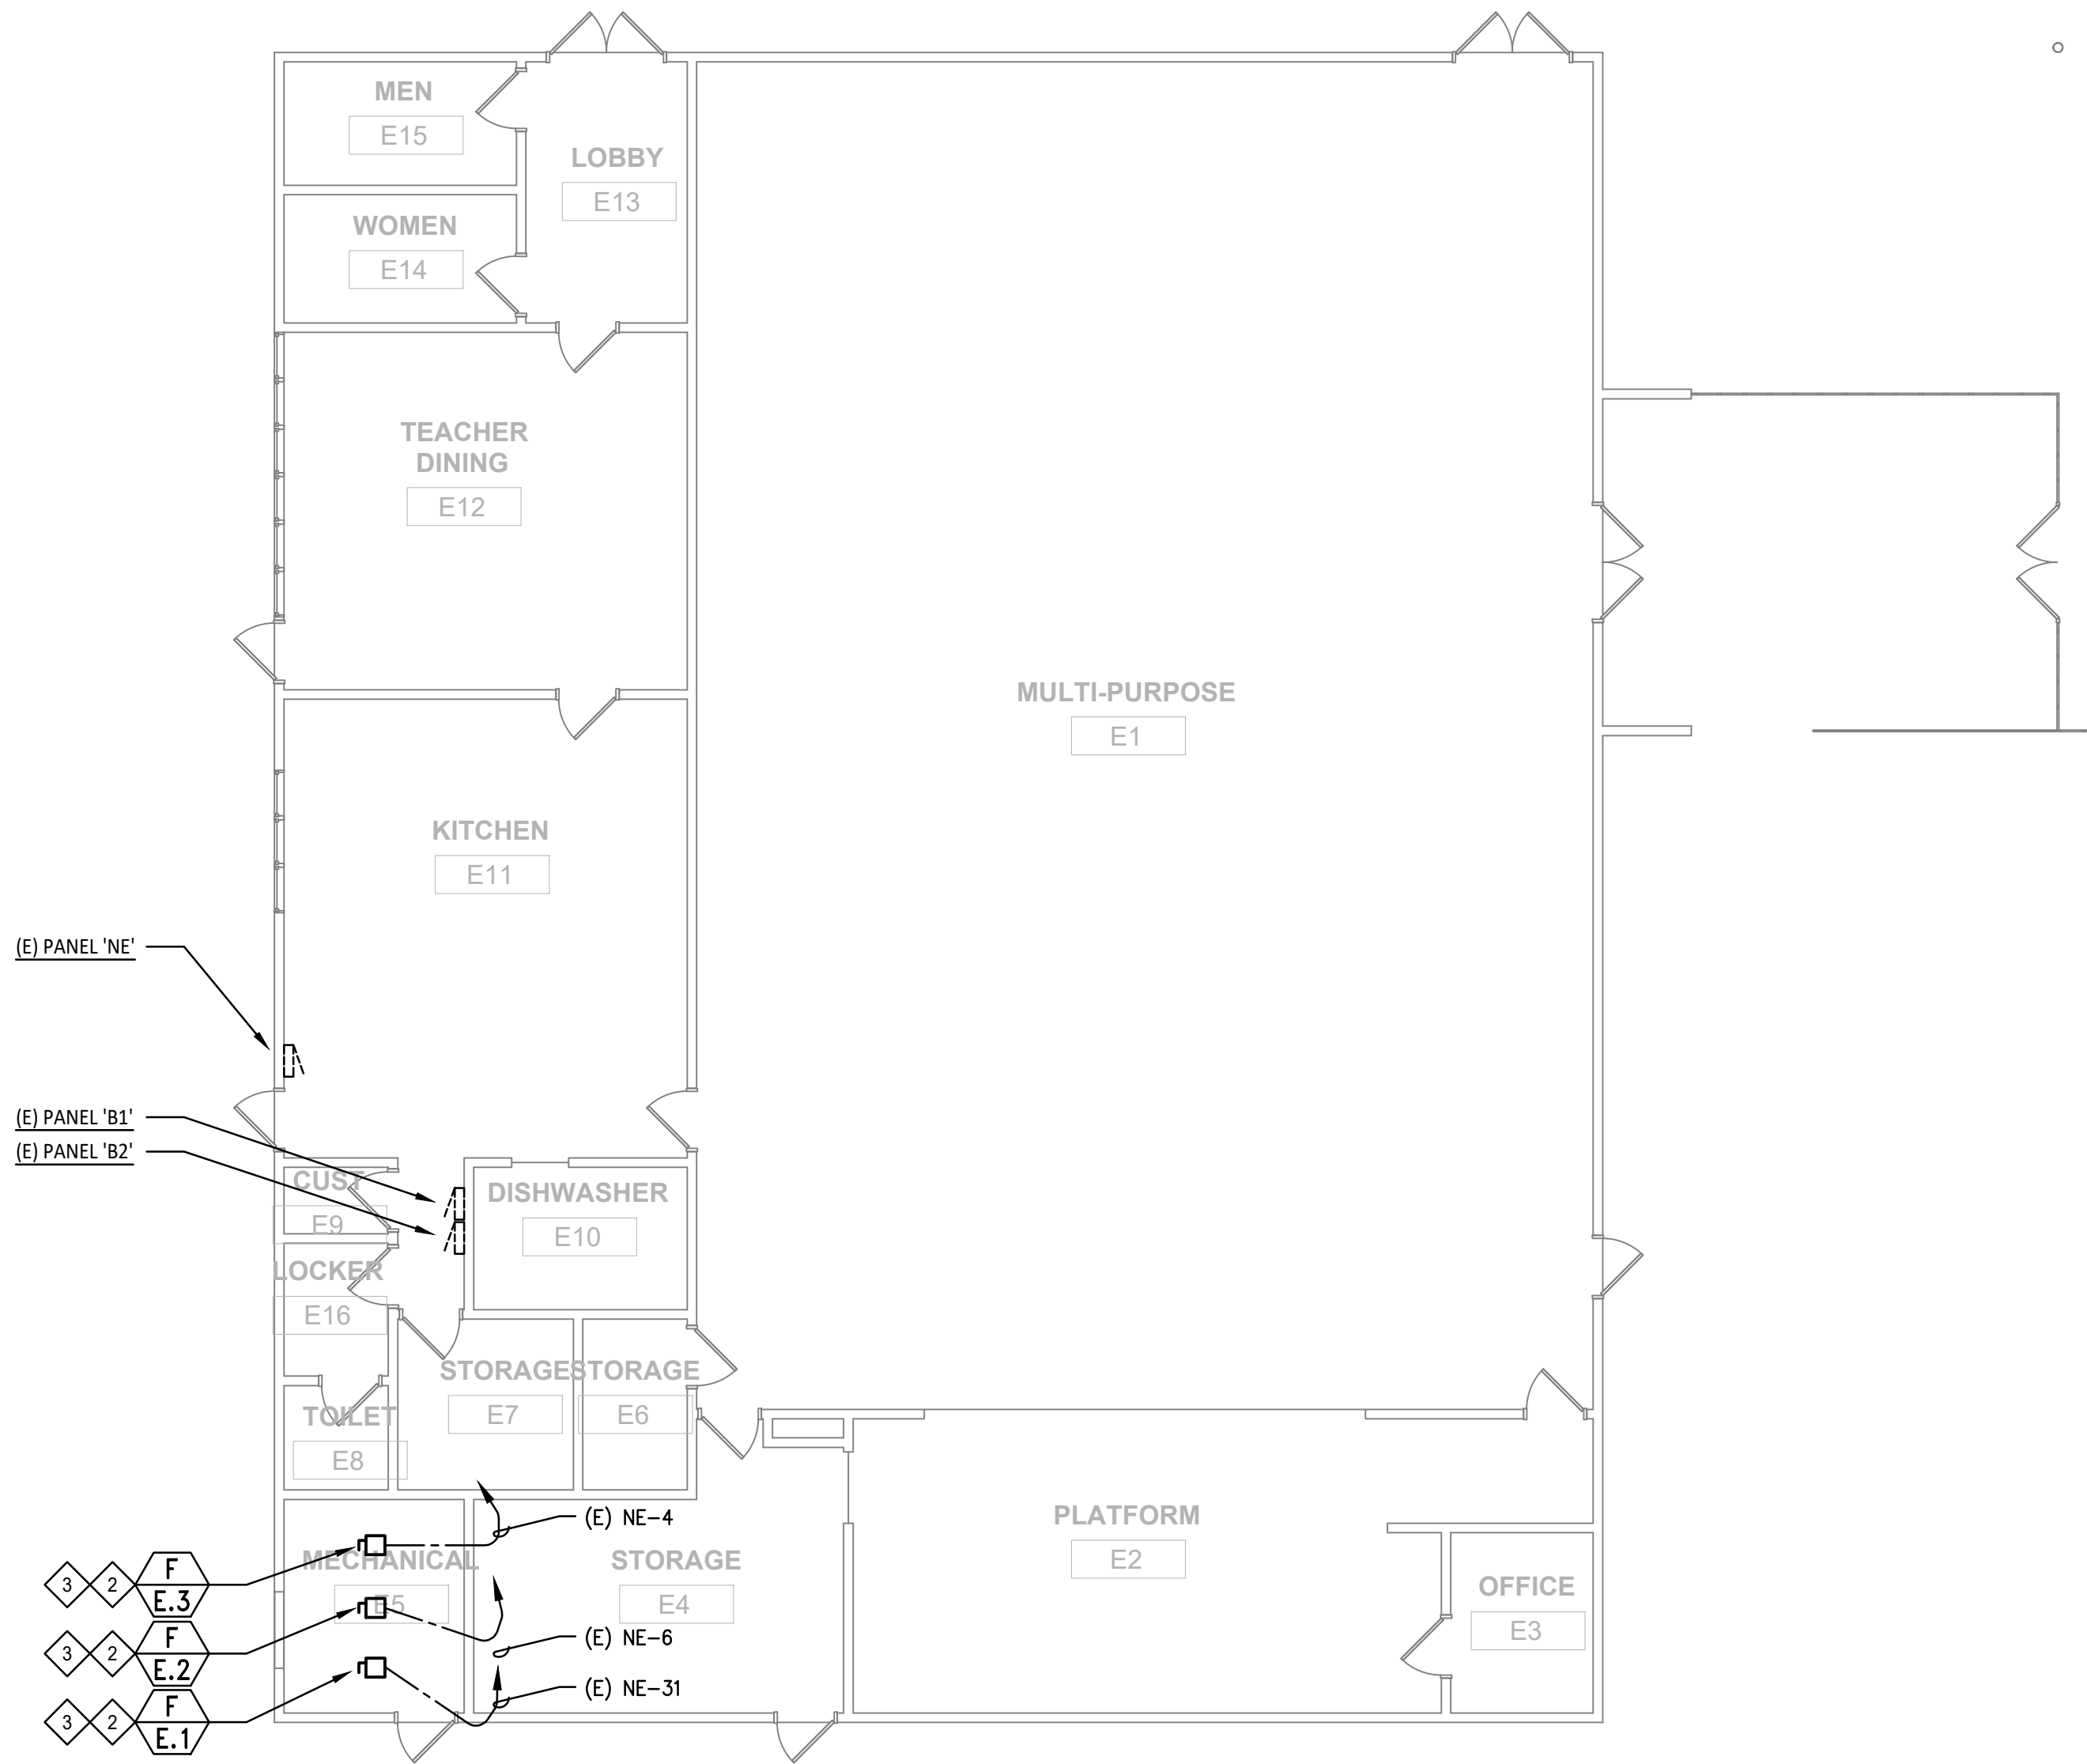

ELECTRICAL POWER PLAN - BUILDING E

1/8" = 1'-0"

2




IF THIS SHEET IS NOT 30"x42". IT IS A REDUCED PRINT; SCALE ACCORDINGLY

IDENTIFICATION STAMP
DIV. OF THE STATE ARCHITECT
APP: 01-122566 INC:
REVIEWED FOR
SS ☒ FLS ☒ ACS ☐
DATE: 3/10/2026



Revisions	Delta	Date	Revisions	By
-----------	-------	------	-----------	----

KEY PLAN

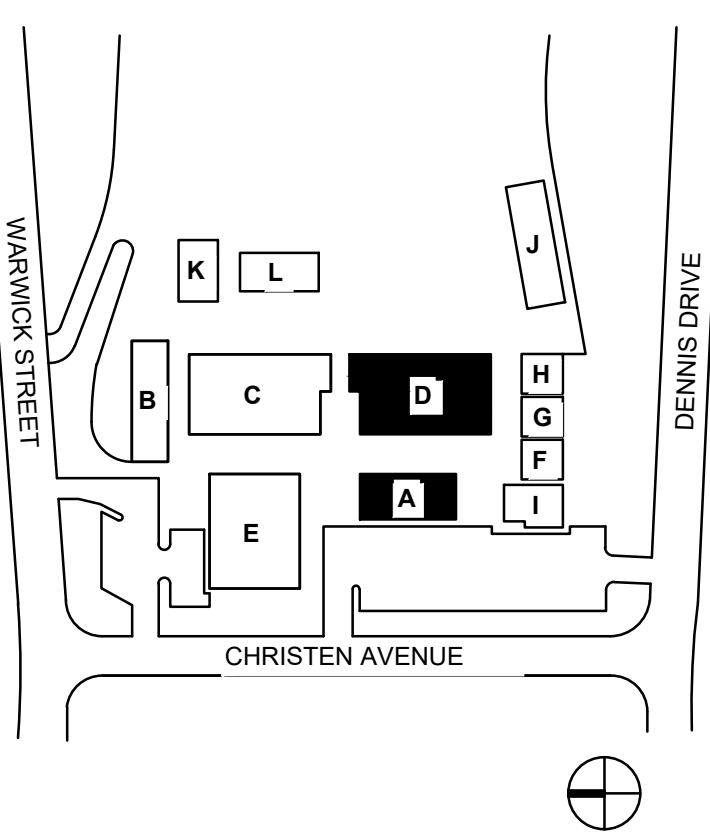

WORM

Electrical Consultants Incorporated
3397 Mt. Diablo Blvd., Suite C
Lafayette, CA 94549
Tel: 925-385-0549
25-004

This document is the property of the Owner and is not to be used without their written permission.



HY **HIBSER YAMAUCHI**
Architects, Inc.
300 - 27th Street
Oakland, CA 94612
510.446.2222 tel / 510.446.2211 fax
HY ARCHITECTS JOB NUMBER XXXX

Facility
SKYLINE ELEMENTARY SCHOOL
55 CHRISTEN AVE, DALY CITY, CA 94015

Project
HVAC REPLACEMENT

Sheet Title
**ELECTRICAL POWER PLANS
BUILDINGS A AND D**

Client Project Number: XXXX

Scale: AS NOTED


Drawn By: DAM

Checked By: TLK

Issue Date: 09/15/25

Revit Version: 2023


E2.03

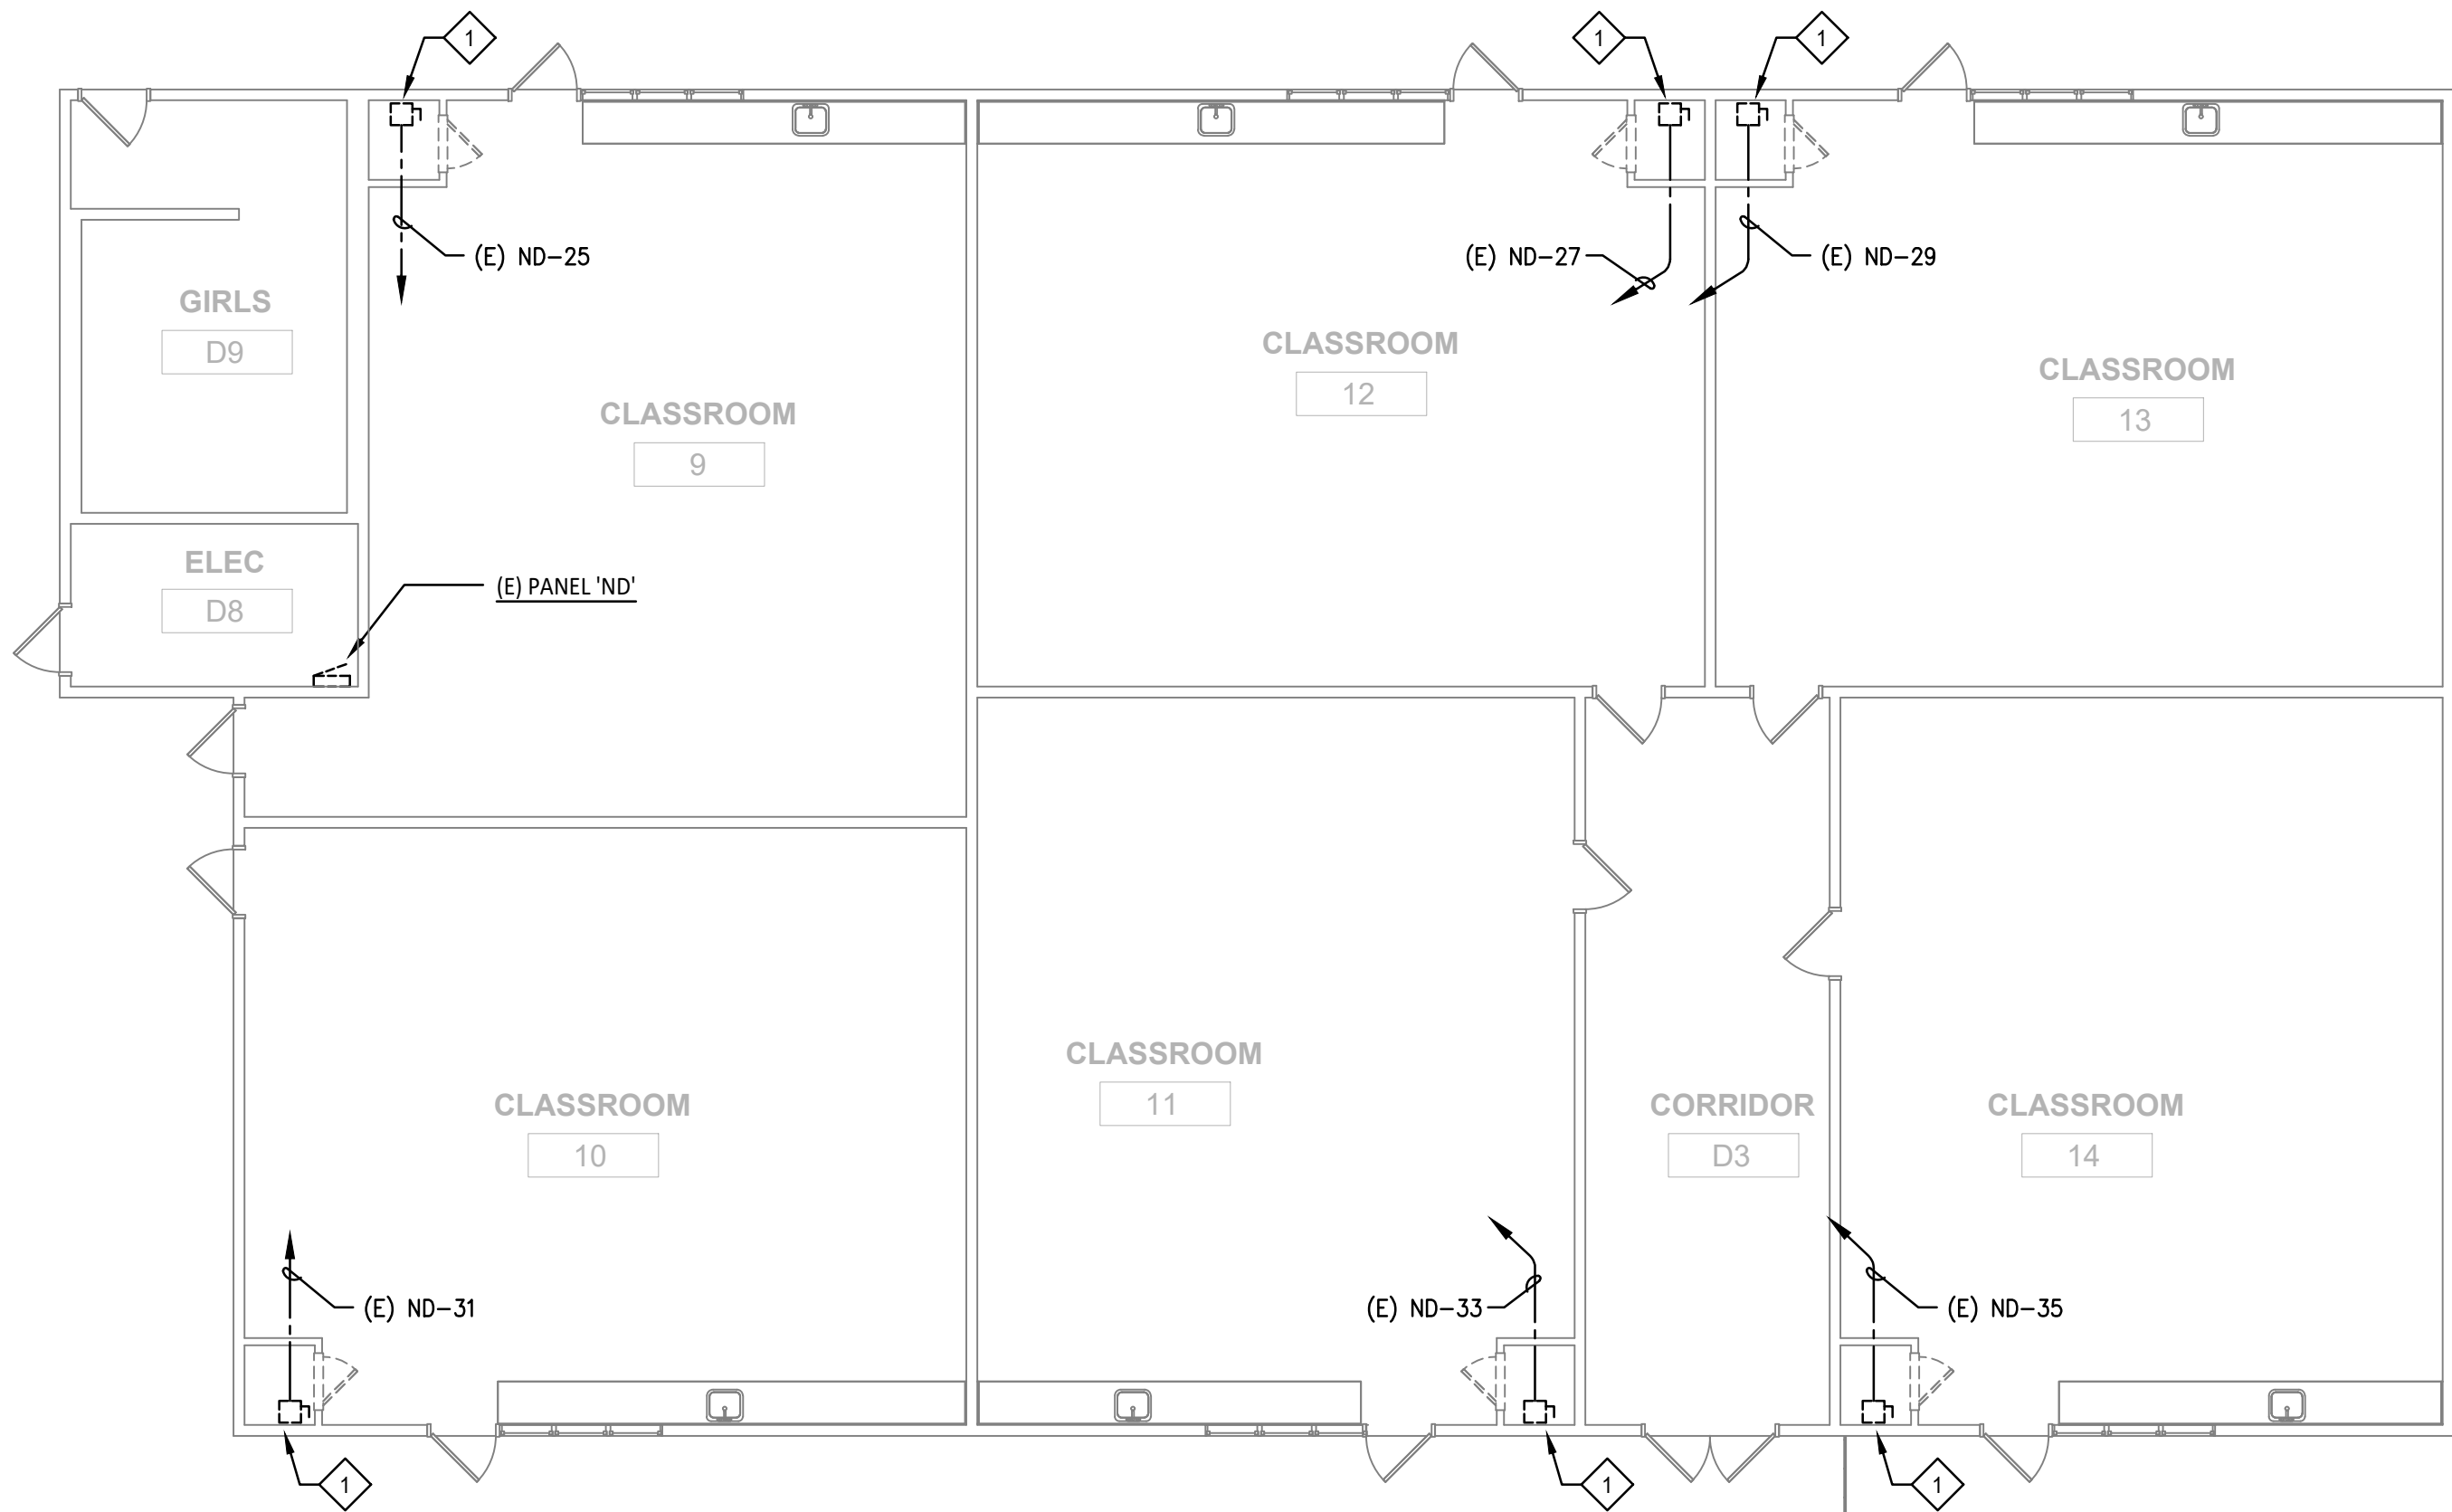

ELECTRICAL DEMOLITION POWER PLAN - BUILDINGS A & D

1/8" = 1'-0"

1

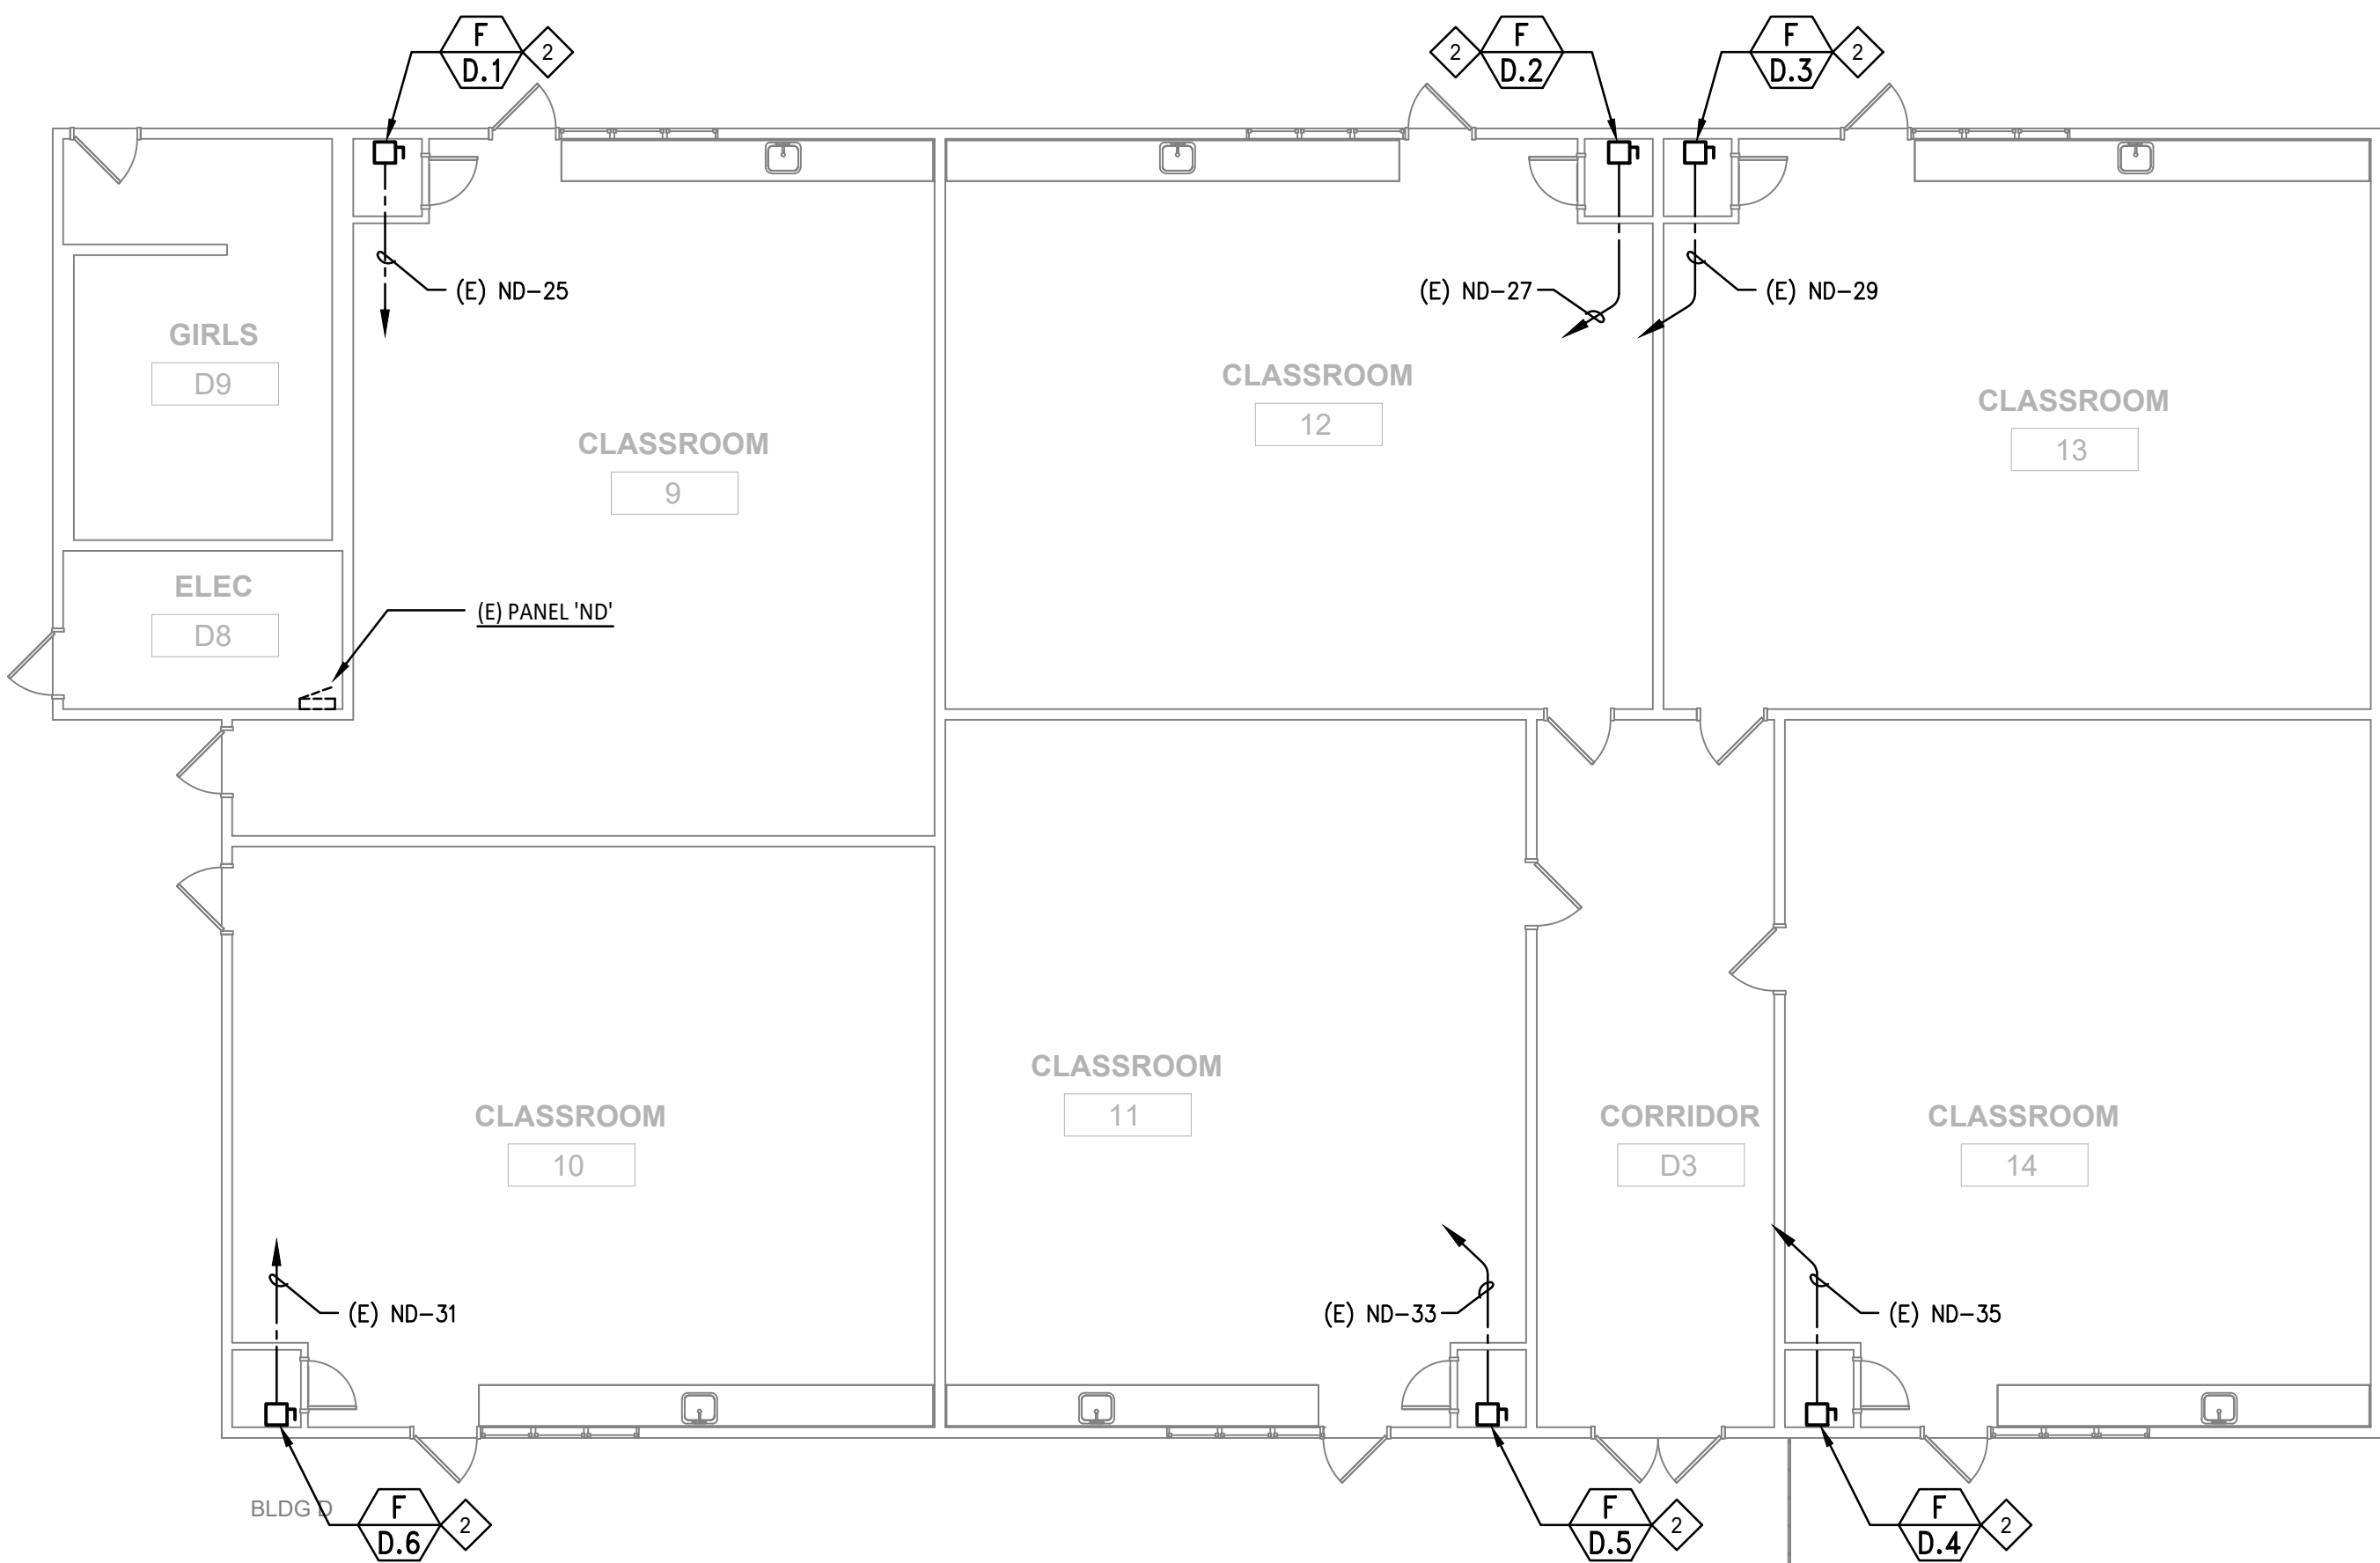

ELECTRICAL POWER PLAN - BUILDINGS A & D

1/8" = 1'-0"

2



IF THIS SHEET IS NOT 30"x42". IT IS A REDUCED PRINT; SCALE ACCORDINGLY

IDENTIFICATION STAMP
DIV. OF THE STATE ARCHITECT
APP: 01-122566 INC:
REVIEWED FOR
SS ☒ FLS ☒ ACS ☐
DATE: 3/10/2026



Revisions	Delta	Date	Revisions	By


GENERAL NOTES

- ALL DISCONNECTS SHOWN ARE TO BE REPLACED WITH NEW. EXTEND EXISTING CIRCUITS AND CONDUCTORS AS REQUIRED AND CONNECT TO EXISTING CIRCUIT.
- EXISTING POWER TO EMS CONTROLLERS ARE TO REMAIN. RECONNECT TO NEW CONTROLLERS. COORDINATE LOCATIONS IN THE FIELD WITH MECHANICAL.

SHEET NOTES

- REPLACE EXISTING RECEPTACLE WITH NEW WEATHERPROOF GFI RECEPTACLE AND RECONNECT TO EXISTING CIRCUIT.
- SEE PANEL SCHEDULE FOR REVISED CIRCUITS.

KEY PLAN

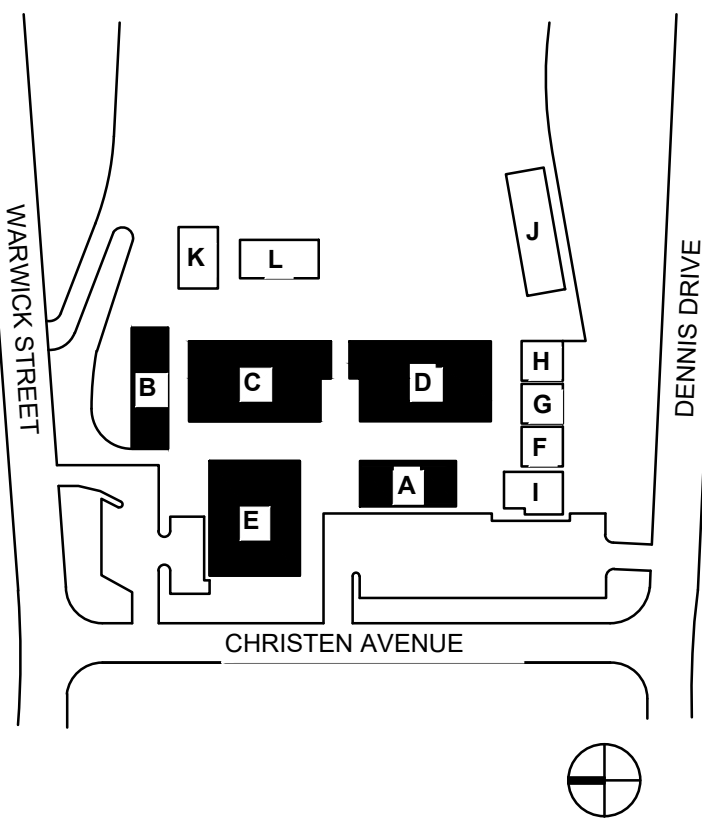

WORM

Electrical Consultants Incorporated
3397 Mt. Diablo Blvd., Suite C
Lafayette, CA 94549
Tel: 925-385-0549
25-004

This document is the property of the Owner and is not to be used without their written permission.



HY HIBSER YAMAUCHI
Architects, Inc.
300 - 27th Street
Oakland, CA 94612
510.446.2222 tel; 510.446.2211 fax

HY ARCHITECTS JOB NUMBER XXXX

Facility
SKYLINE ELEMENTARY SCHOOL
55 CHRISTEN AVE, DALY CITY, CA 94015

Project
HVAC REPLACEMENT

Sheet Title
ELECTRICAL POWER PLAN - ROOF

Client Project Number: XXXX

Scale: AS NOTED


Drawn By: DAM

Checked By: TLK

Issue Date: 09/15/25

Revit Version: 2023

E2.04

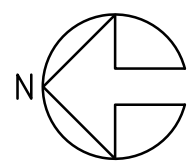

ELECTRICAL POWER PLAN - ROOF

1" = 10'-0"

1




IF THIS SHEET IS NOT 30"x42". IT IS A
REDUCED PRINT; SCALE ACCORDINGLY

IDENTIFICATION STAMP
DIV. OF THE STATE ARCHITECT
APP: 01-122566 INC:
REVIEWED FOR
SS ☒ FLS ☒ ACS ☐
DATE: 3/10/2026



Revisions	Delta	Date	Revisions	By

KEY PLAN

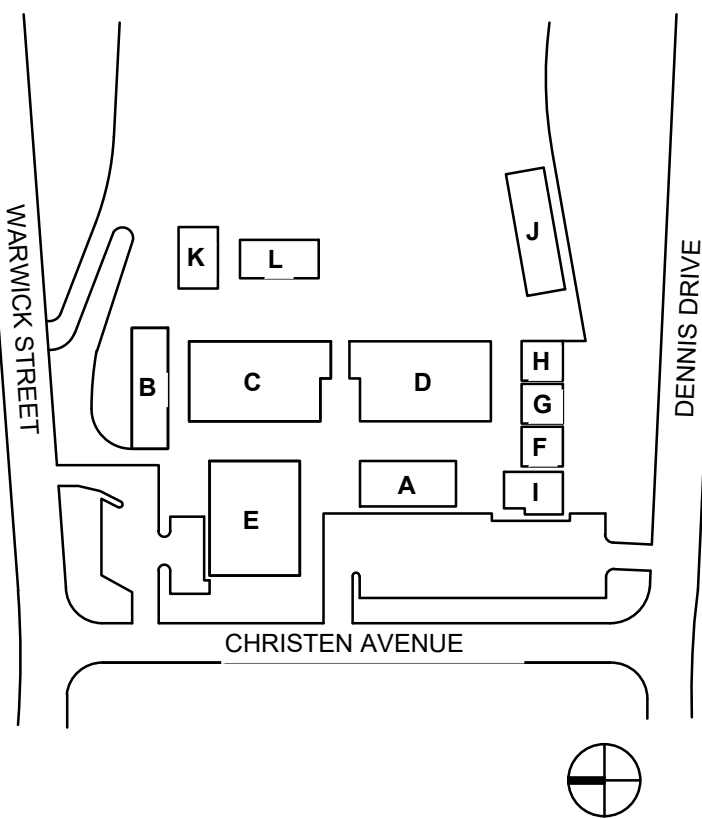

WORM

Electrical Consultants Incorporated
3397 Mt. Diablo Blvd., Suite C
Lafayette, CA 94549
Tel: 925-385-0549
25-004

This document is the property of the Owner and is not to be used without their written permission.



HY HIBSER YAMAUCHI
Architects, Inc.
300 - 27th Street
Oakland, CA 94612
510.446.2222 tel | 510.446.2211 fax

HY ARCHITECTS JOB NUMBER XXXX

Facility
SKYLINE ELEMENTARY SCHOOL
55 CHRISTEN AVE, DALY CITY, CA 94015

Project
HVAC REPLACEMENT


Sheet Title
FIRE ALARM RISER DIAGRAM

Client Project Number: XXXX

Scale: AS NOTED
Drawn By: DAM
Checked By: TLK
Issue Date: 09/15/25
Revit Version: 2023

FA0.02

EXISTING SYSTEM
APPROVED DSA APPL
#01-100221

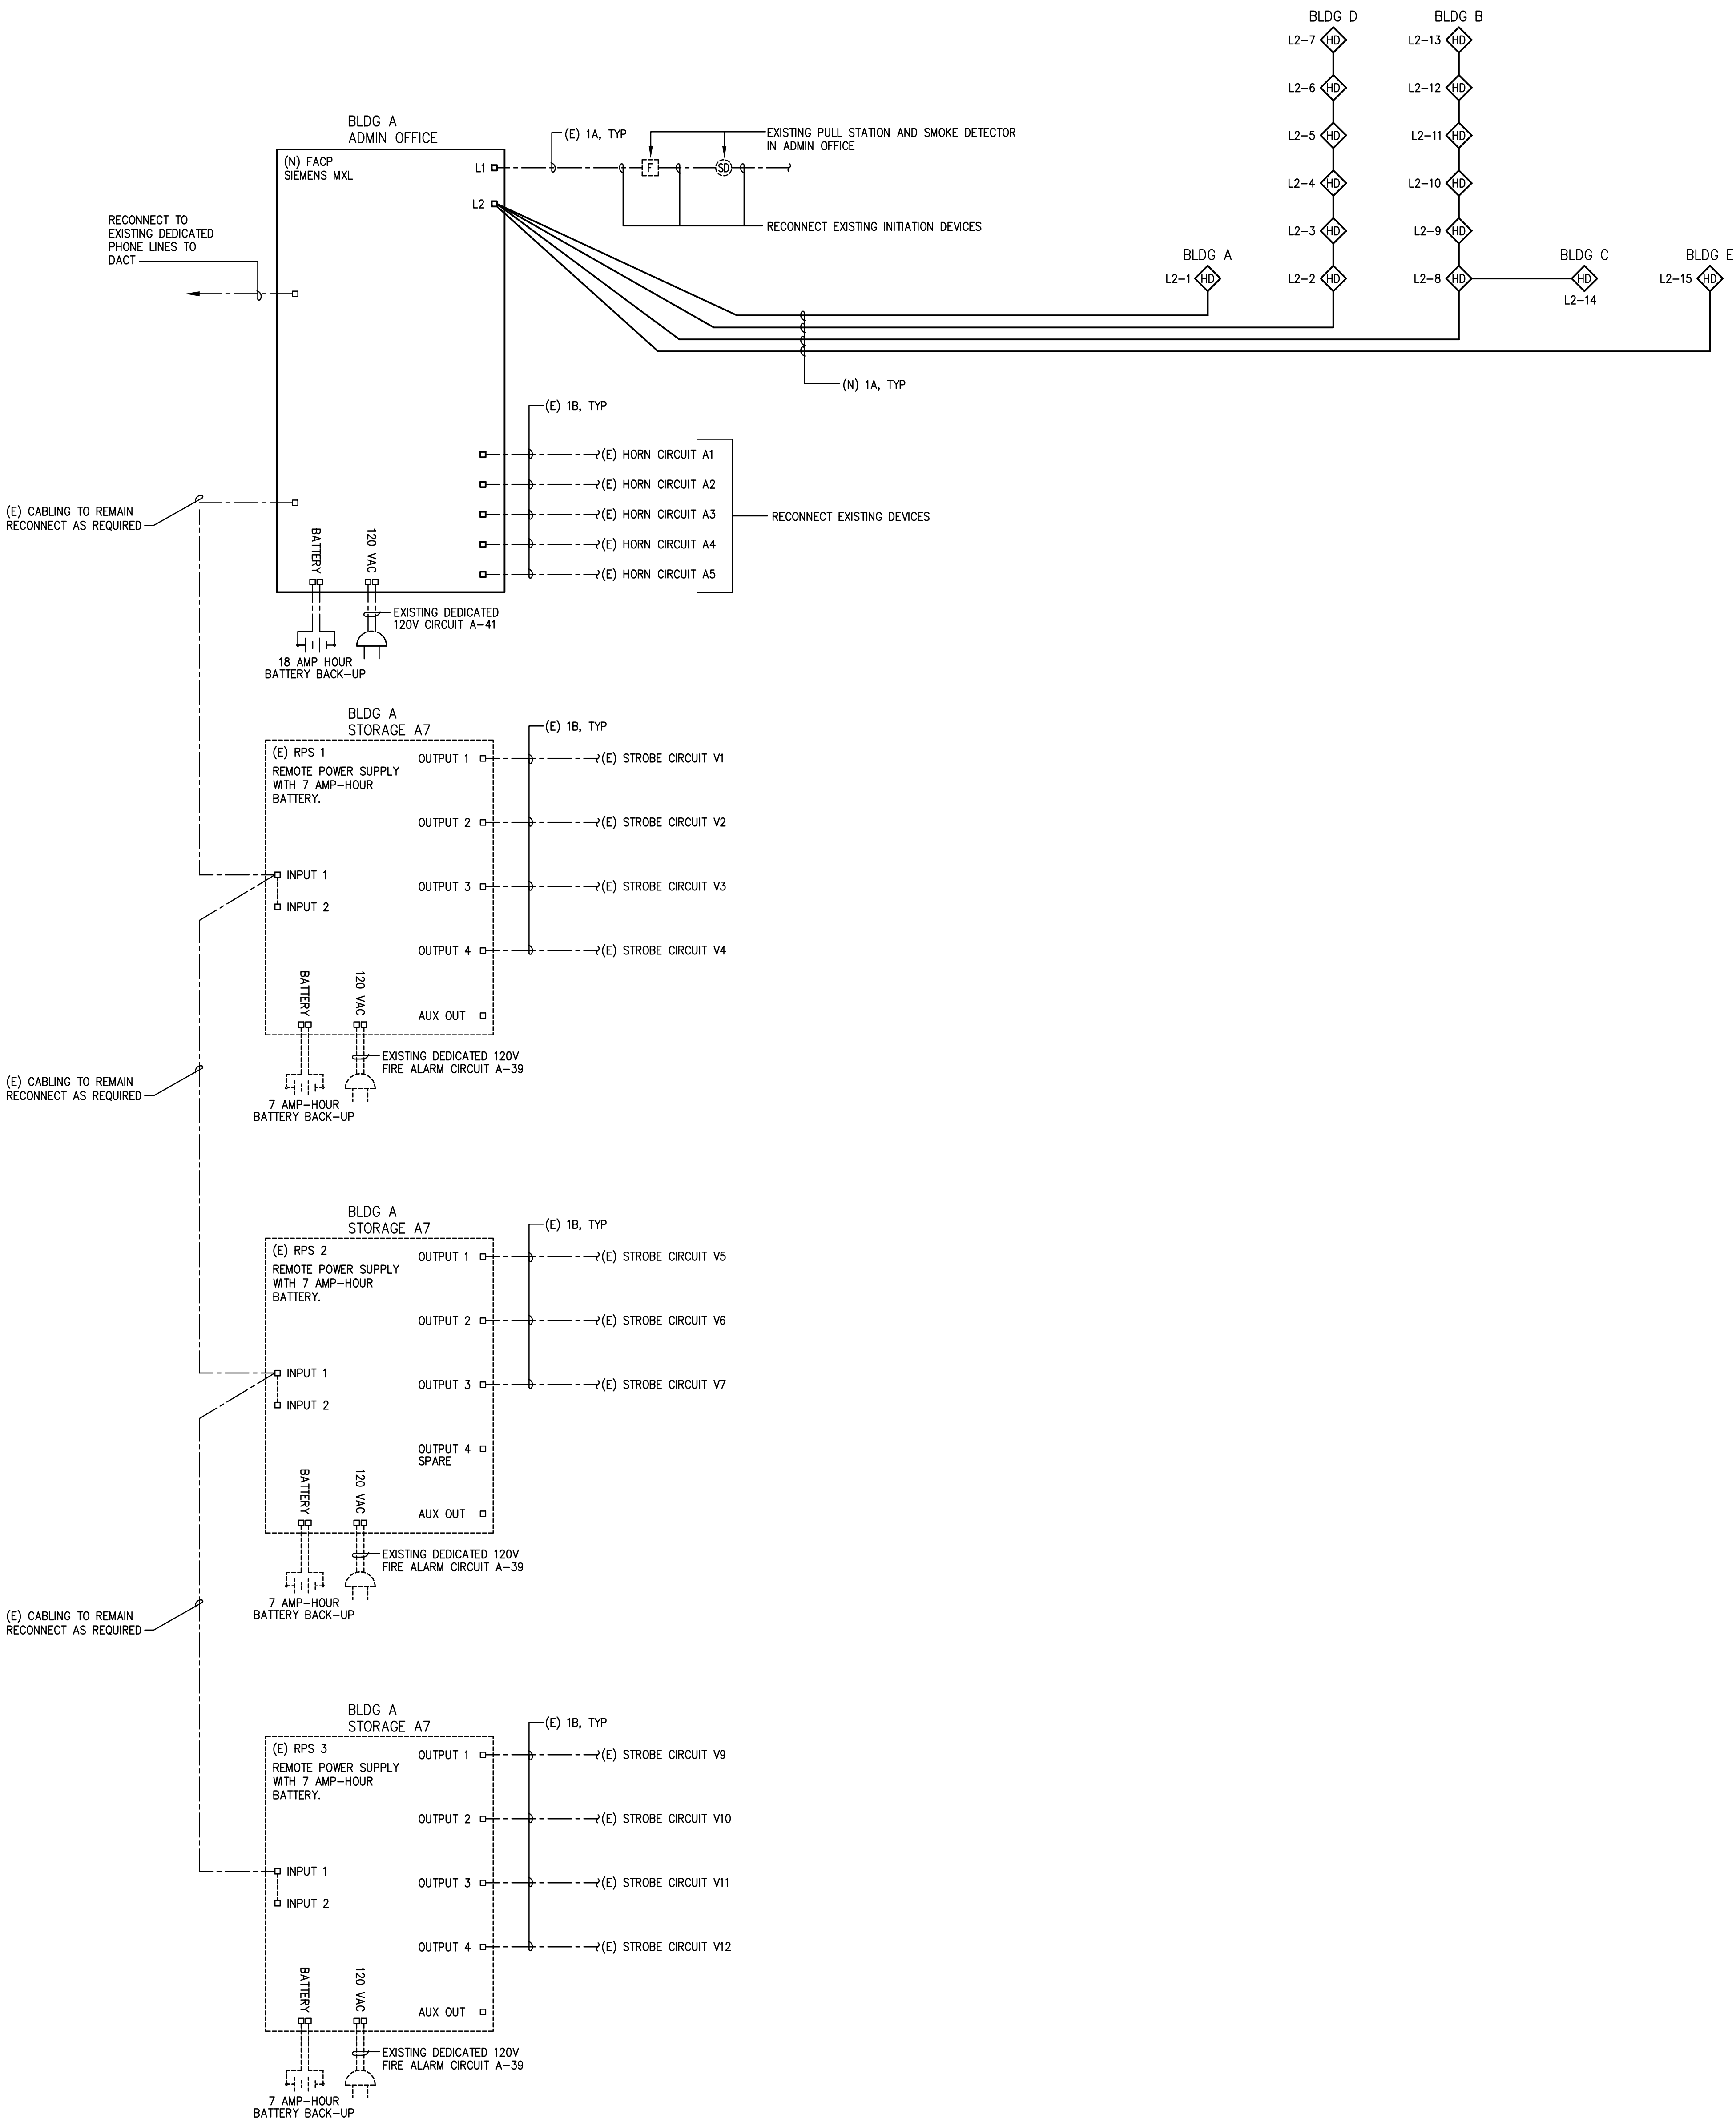




IF THIS SHEET IS NOT 30"x42". IT IS A
REDUCED PRINT; SCALE ACCORDINGLY

IDENTIFICATION STAMP
DIV. OF THE STATE ARCHITECT
APP: 01-122566 INC:
REVIEWED FOR
SS ☒ FLS ☒ ACS ☐
DATE: 3/10/2026




Revisions	Delta	Date	Revisions	By

KEY PLAN

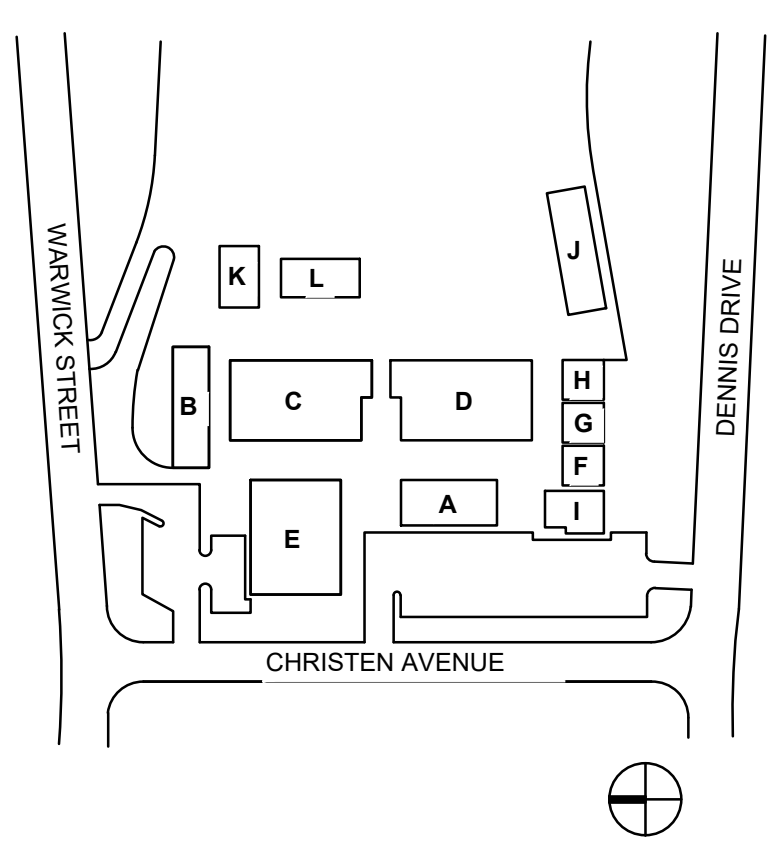

Electrical Consultants Incorporated
3397 Mt. Diablo Blvd., Suite C
Lafayette, CA 94549
Tel: 925-385-0549
25-004

This document is the property of the Owner and is not to be used without their written permission.

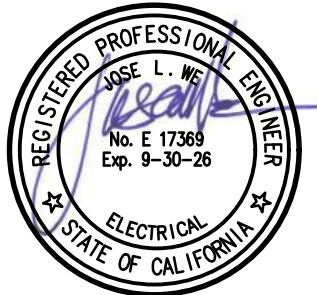

HY HIBSER YAMAUCHI
Architects, Inc.
300 - 27th Street
Oakland, CA 94612
510.446.2222 tel | 510.446.2211 fax

HY ARCHITECTS JOB NUMBER XXXX

Facility
SKYLINE ELEMENTARY SCHOOL
55 CHRISTEN AVE, DALY CITY, CA 94015


Project
HVAC REPLACEMENT

Sheet Title
FIRE ALARM SITE PLAN

Client Project Number: XXXX

Scale: AS NOTED	Sheet
Drawn By: DAM	FA1.01
Checked By: TLK	
Issue Date: 09/15/25	
Revit Version: 2023	

2/12/2026 6:17 AM c:\user\damon\wrm consulting\dropbox\cad\2025\25-004 skyline es hvac\25004 fa1.01

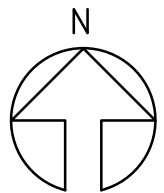

FIRE ALARM SITE PLAN 1" = 20'-0" 1




IF THIS SHEET IS NOT 30"x42". IT IS A
REDUCED PRINT; SCALE ACCORDINGLY

IDENTIFICATION STAMP
DIV. OF THE STATE ARCHITECT
APP: 01-122566 INC:
REVIEWED FOR
SS ☒ FLS ☒ ACS ☐
DATE: 3/10/2026



Revisions	Delta	Date	Revisions	By

KEY PLAN

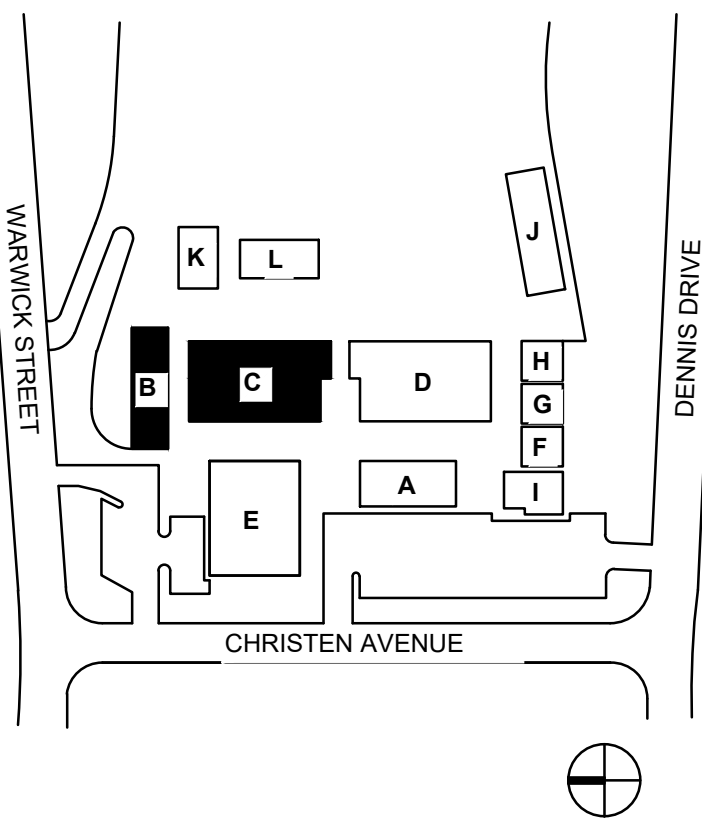

Electrical Consultants Incorporated
3397 Mt. Diablo Blvd., Suite C
Lafayette, CA 94549
Tel: 925-385-0549
25-004

This document is the property of the Owner and is not to be used without their written permission.



HY

HIBSER YAMAUCHI
Architects, Inc.

300 - 27th Street
Oakland, CA 94612
510.446.2222 tel | 510.446.2211 fax

HY ARCHITECTS JOB NUMBER XXXX

Facility
SKYLINE ELEMENTARY SCHOOL
55 CHRISTEN AVE, DALY CITY, CA 94015



Project
HVAC REPLACEMENT

Sheet Title
FIRE ALARM PLANS
BUILDINGS B AND C

Client Project Number: XXXX

Scale: AS NOTED
Drawn By: DAM
Checked By: TLK
Issue Date: 09/15/25
Revit Version: 2023

FA2.01

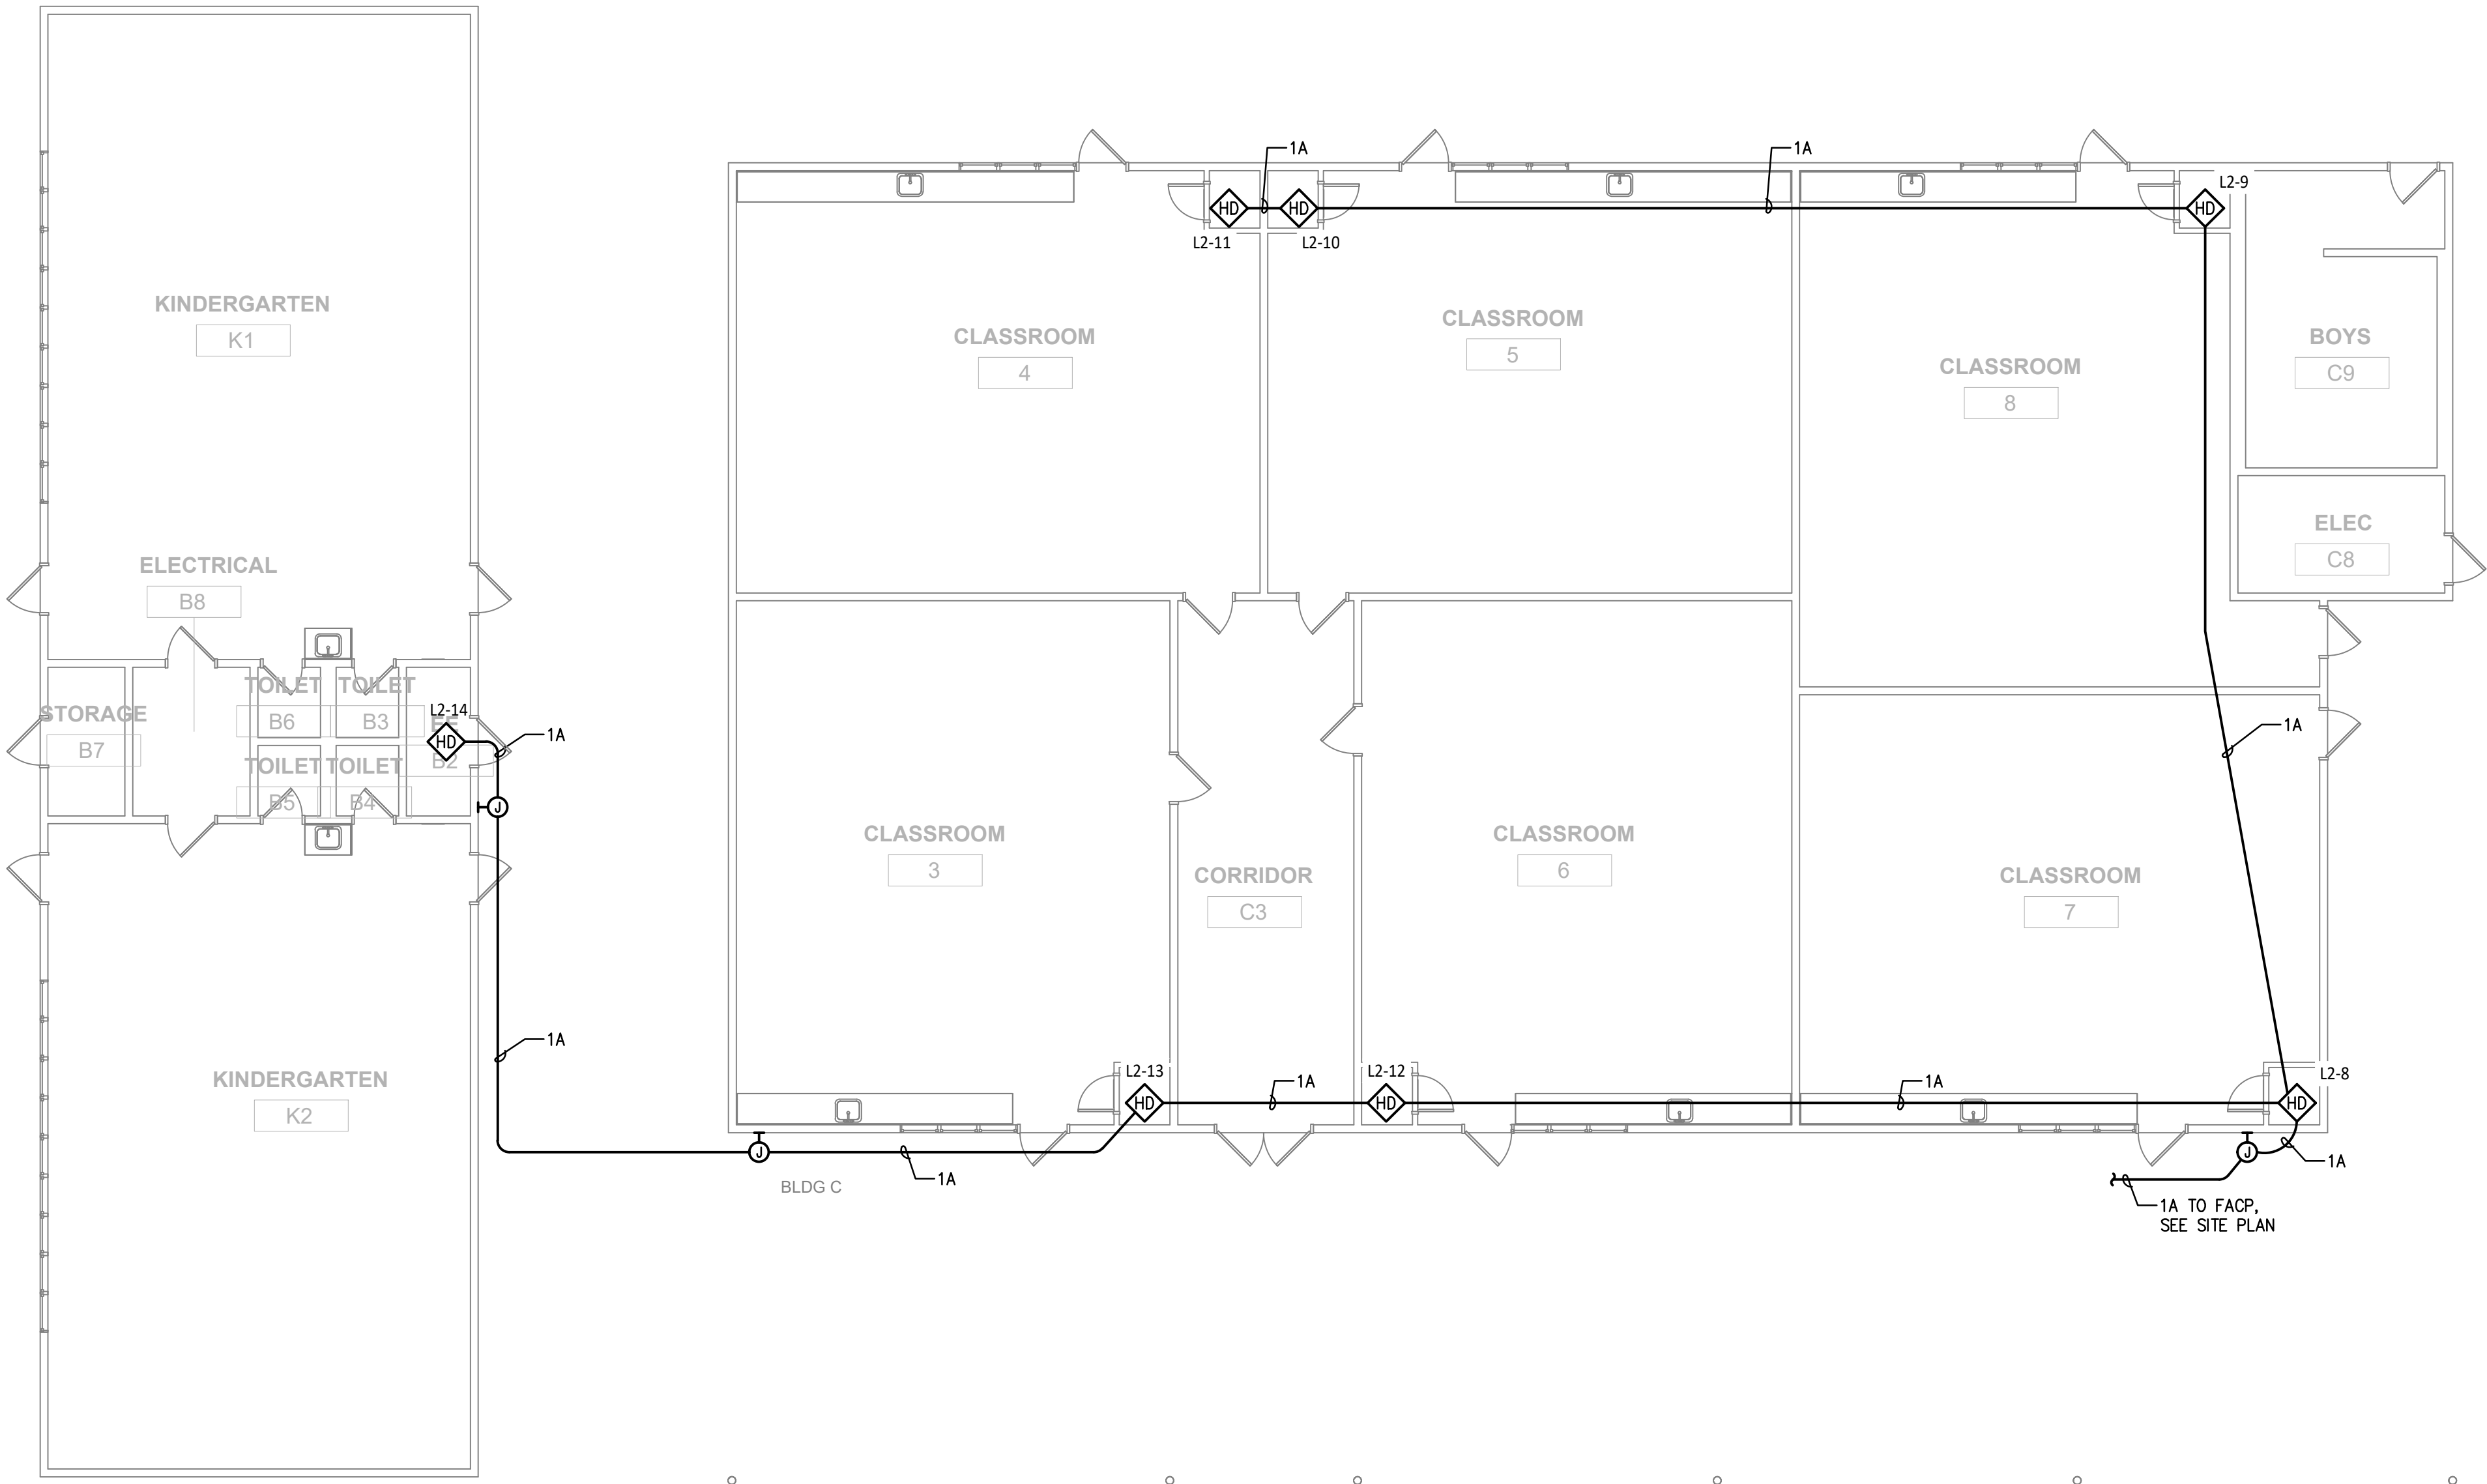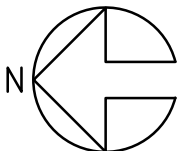

FIRE ALARM PLAN - BUILDINGS B & C

1/8" = 1'-0"

1

2/12/2026 6:17 AM c:\user\damon\wrm consulting\dropbox\cad\2025\25-004 skyline es hvae\25004 fa2.01




IF THIS SHEET IS NOT 30"x42". IT IS A REDUCED PRINT; SCALE ACCORDINGLY

IDENTIFICATION STAMP
DIV. OF THE STATE ARCHITECT
APP: 01-122566 INC:
REVIEWED FOR
SS ☒ FLS ☒ ACS ☐
DATE: 3/10/2026



Revisions			
Delta	Date	Revisions	By

KEY PLAN

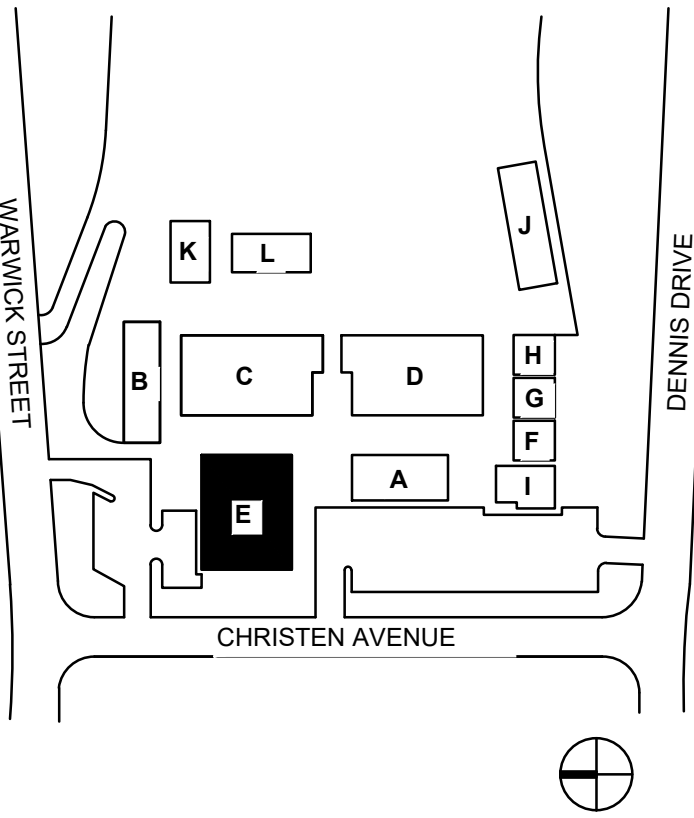

WORM
Electrical Consultants Incorporated
3397 Mt. Diablo Blvd., Suite C
Lafayette, CA 94549
Tel: 925-385-0549
25-004

This document is the property of the Owner and is not to be used without their written permission.





HY HIBSER YAMAUCHI
Architects, Inc.
300 - 27th Street
Oakland, CA 94612
510.446.2222 tel | 510.446.2211 fax
HY ARCHITECTS JOB NUMBER XXXX

Facility
SKYLINE ELEMENTARY SCHOOL
55 CHRISTEN AVE, DALY CITY, CA 94015

Project
HVAC REPLACEMENT

Sheet Title
FIRE ALARM PLANS
BUILDING E

Client Project Number:		XXXX
Scale:	AS NOTED	Sheet FA2.02
Drawn By:	DAM	
Checked By:	TLK	
Issue Date:	09/15/25	
Revit Version: 2023		

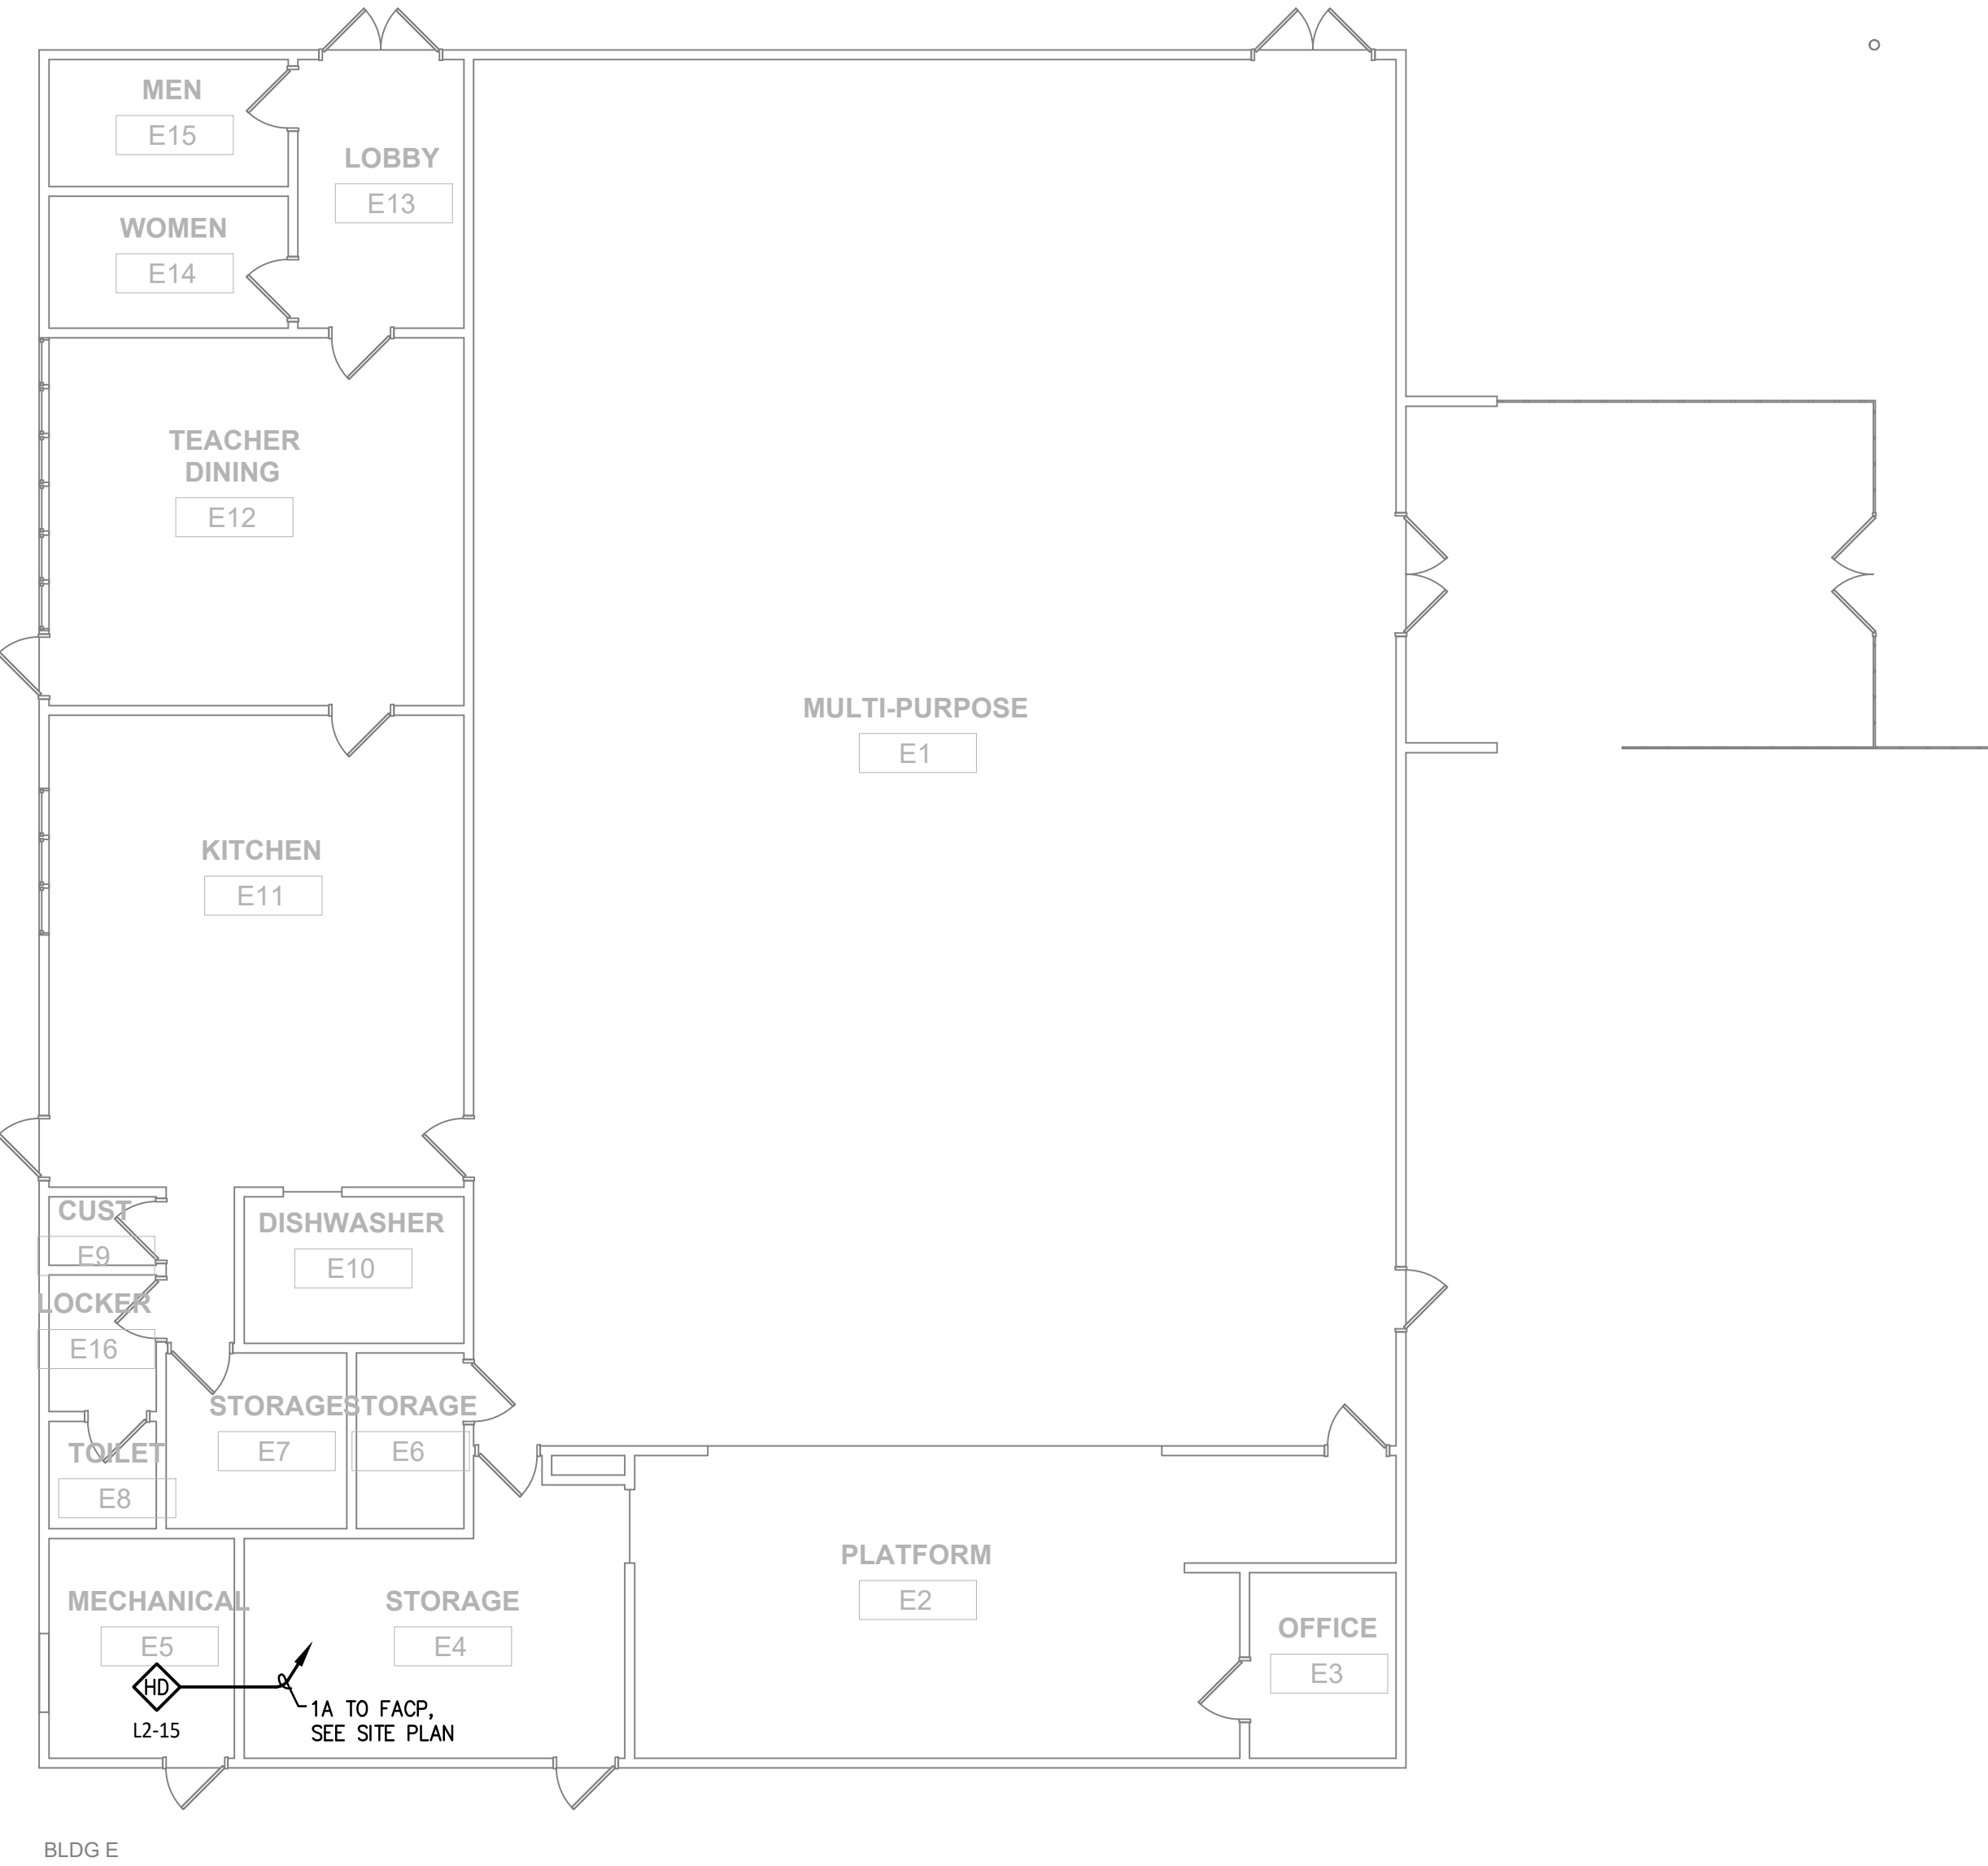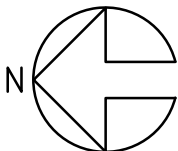




IF THIS SHEET IS NOT 30"x42". IT IS A REDUCED PRINT; SCALE ACCORDINGLY

IDENTIFICATION STAMP
DIV. OF THE STATE ARCHITECT
APP: 01-122566 INC:
REVIEWED FOR
SS ☒ FLS ☒ ACS ☐
DATE: 3/10/2026



Revisions			
Delta	Date	Revisions	By

KEY PLAN

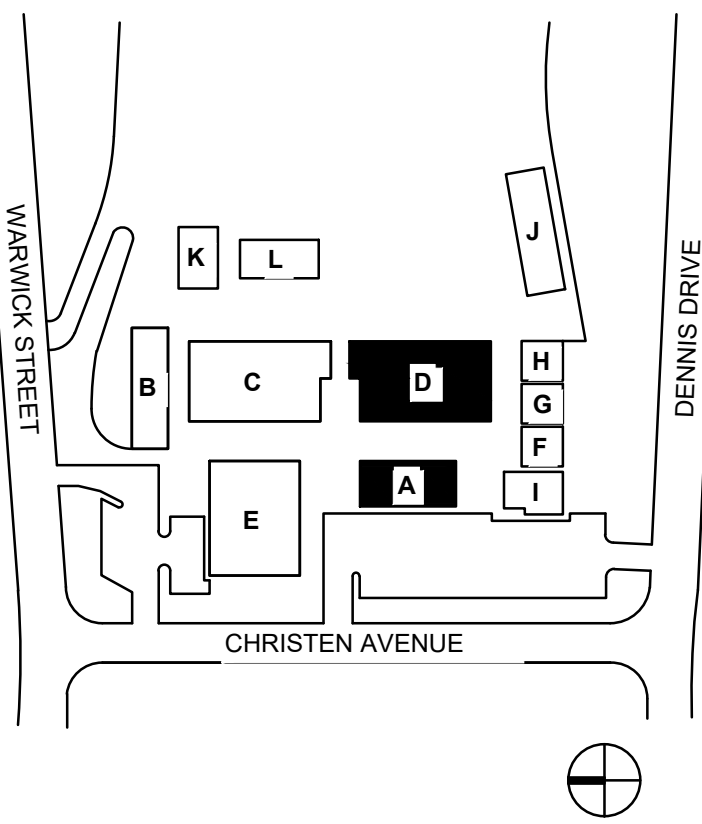

WORM

Electrical Consultants Incorporated
3397 Mt. Diablo Blvd., Suite C
Lafayette, CA 94549
Tel: 925-385-0549
25-004

This document is the property of the Owner and is not to be used without their written permission.



HY HIBSER YAMAUCHI
Architects, Inc.
300 - 27th Street
Oakland, CA 94612
510.446.2222 tel; 510.446.2211 fax

HY ARCHITECTS JOB NUMBER XXXX

Facility
SKYLINE ELEMENTARY SCHOOL
55 CHRISTEN AVE, DALY CITY, CA 94015

Project
HVAC REPLACEMENT

Sheet Title
FIRE ALARM PLANS
BUILDINGS A AND D

Client Project Number: XXXX

Scale: AS NOTED


Drawn By: DAM

Checked By: TLK

Issue Date: 09/15/25

Revit Version: 2023

FA2.03

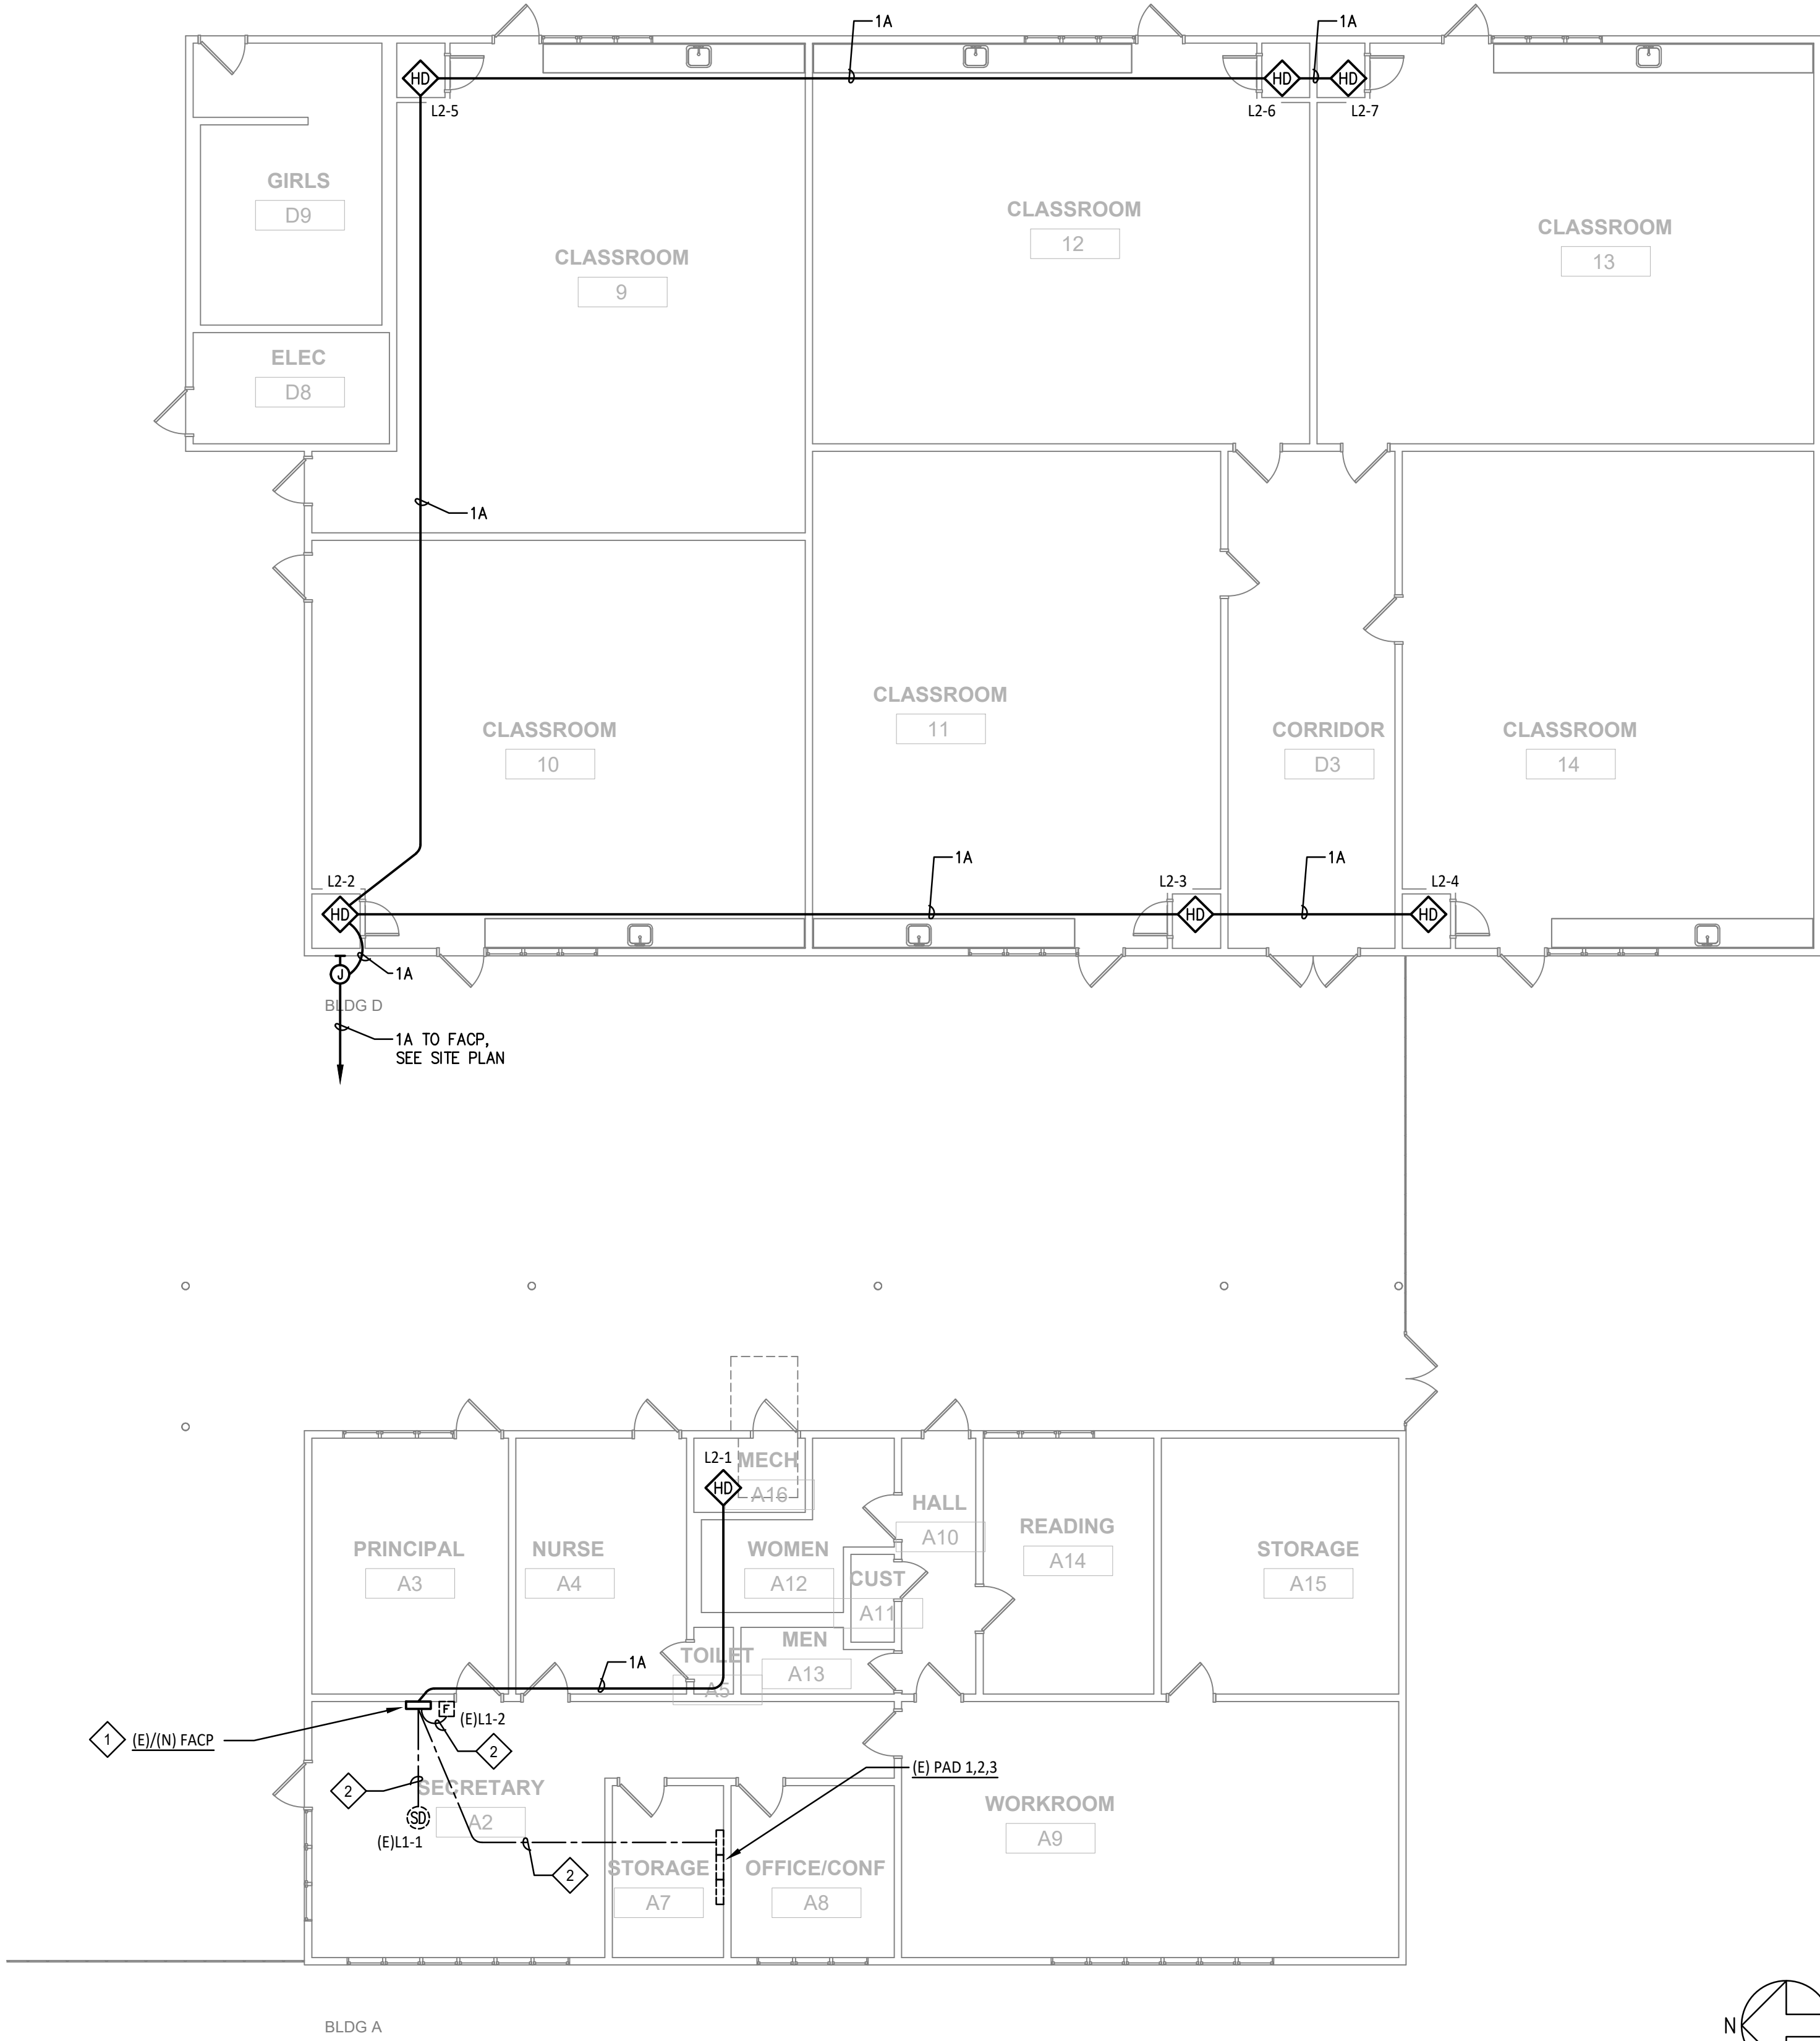

FIRE ALARM PLAN - BUILDINGS A & D

1/8" = 1'-0"

1

2/12/2026 6:17 AM c:\user\damon\wrm consulting\dropbox\cad\2025\25-004_skyline es hvac\25004 fa2.03