



## **BID ADDENDUM NO. 02**

**Date: March 26, 2026**

To Drawings and Specifications dated **May 15, 2025**.

### **Project location**

# **Bridge Classroom Portables – Multiple Sites – Lakewood Elementary School**

1100 N Ham Lane  
Lodi, CA 95242

Prepared by: **PBK**  
1110 Iron Point Road, Suite 200  
Folsom, California 95630

PBK Project No.: 250048

- A. Receipt of this Addendum shall be acknowledged on the Bid Form.
- B. This Addendum forms part of the Contract documents for the above referenced project and shall be incorporated integrally therewith.
- C. Each bidder shall make necessary adjustments and submit this proposal with full knowledge of all modifications, clarifications, and supplemental data included therein. Where provisions of the following supplemental data differ from those of the original Contract Documents, this Addendum shall govern.
- D. Clarification:

### **VOLUME 1 – BIDDING AND CONTRACT REQUIREMENTS: N/A**

None -

### **VOLUME 2 – SPECIFICATIONS:**

None -

### **DRAWINGS:**

**Item No. 01** Replace in its entirety Technology Drawing T201. Location of data port has moved.


**Item No. 02** Replace in its entirety Technology Drawing T601. Exterior Camera Wall Mount detail 03 has been modified.

### **RFI LOG:**

- 1. Is the Contractor responsible for patch back on the grass area?
  - a. Yes, the contractor is responsible to repair any grass and/or irrigation that is damaged during construction as well as any other surfaces or installations that have been damaged.

**End of Addendum No. 02**

**END OF SECTION 00 00 74**

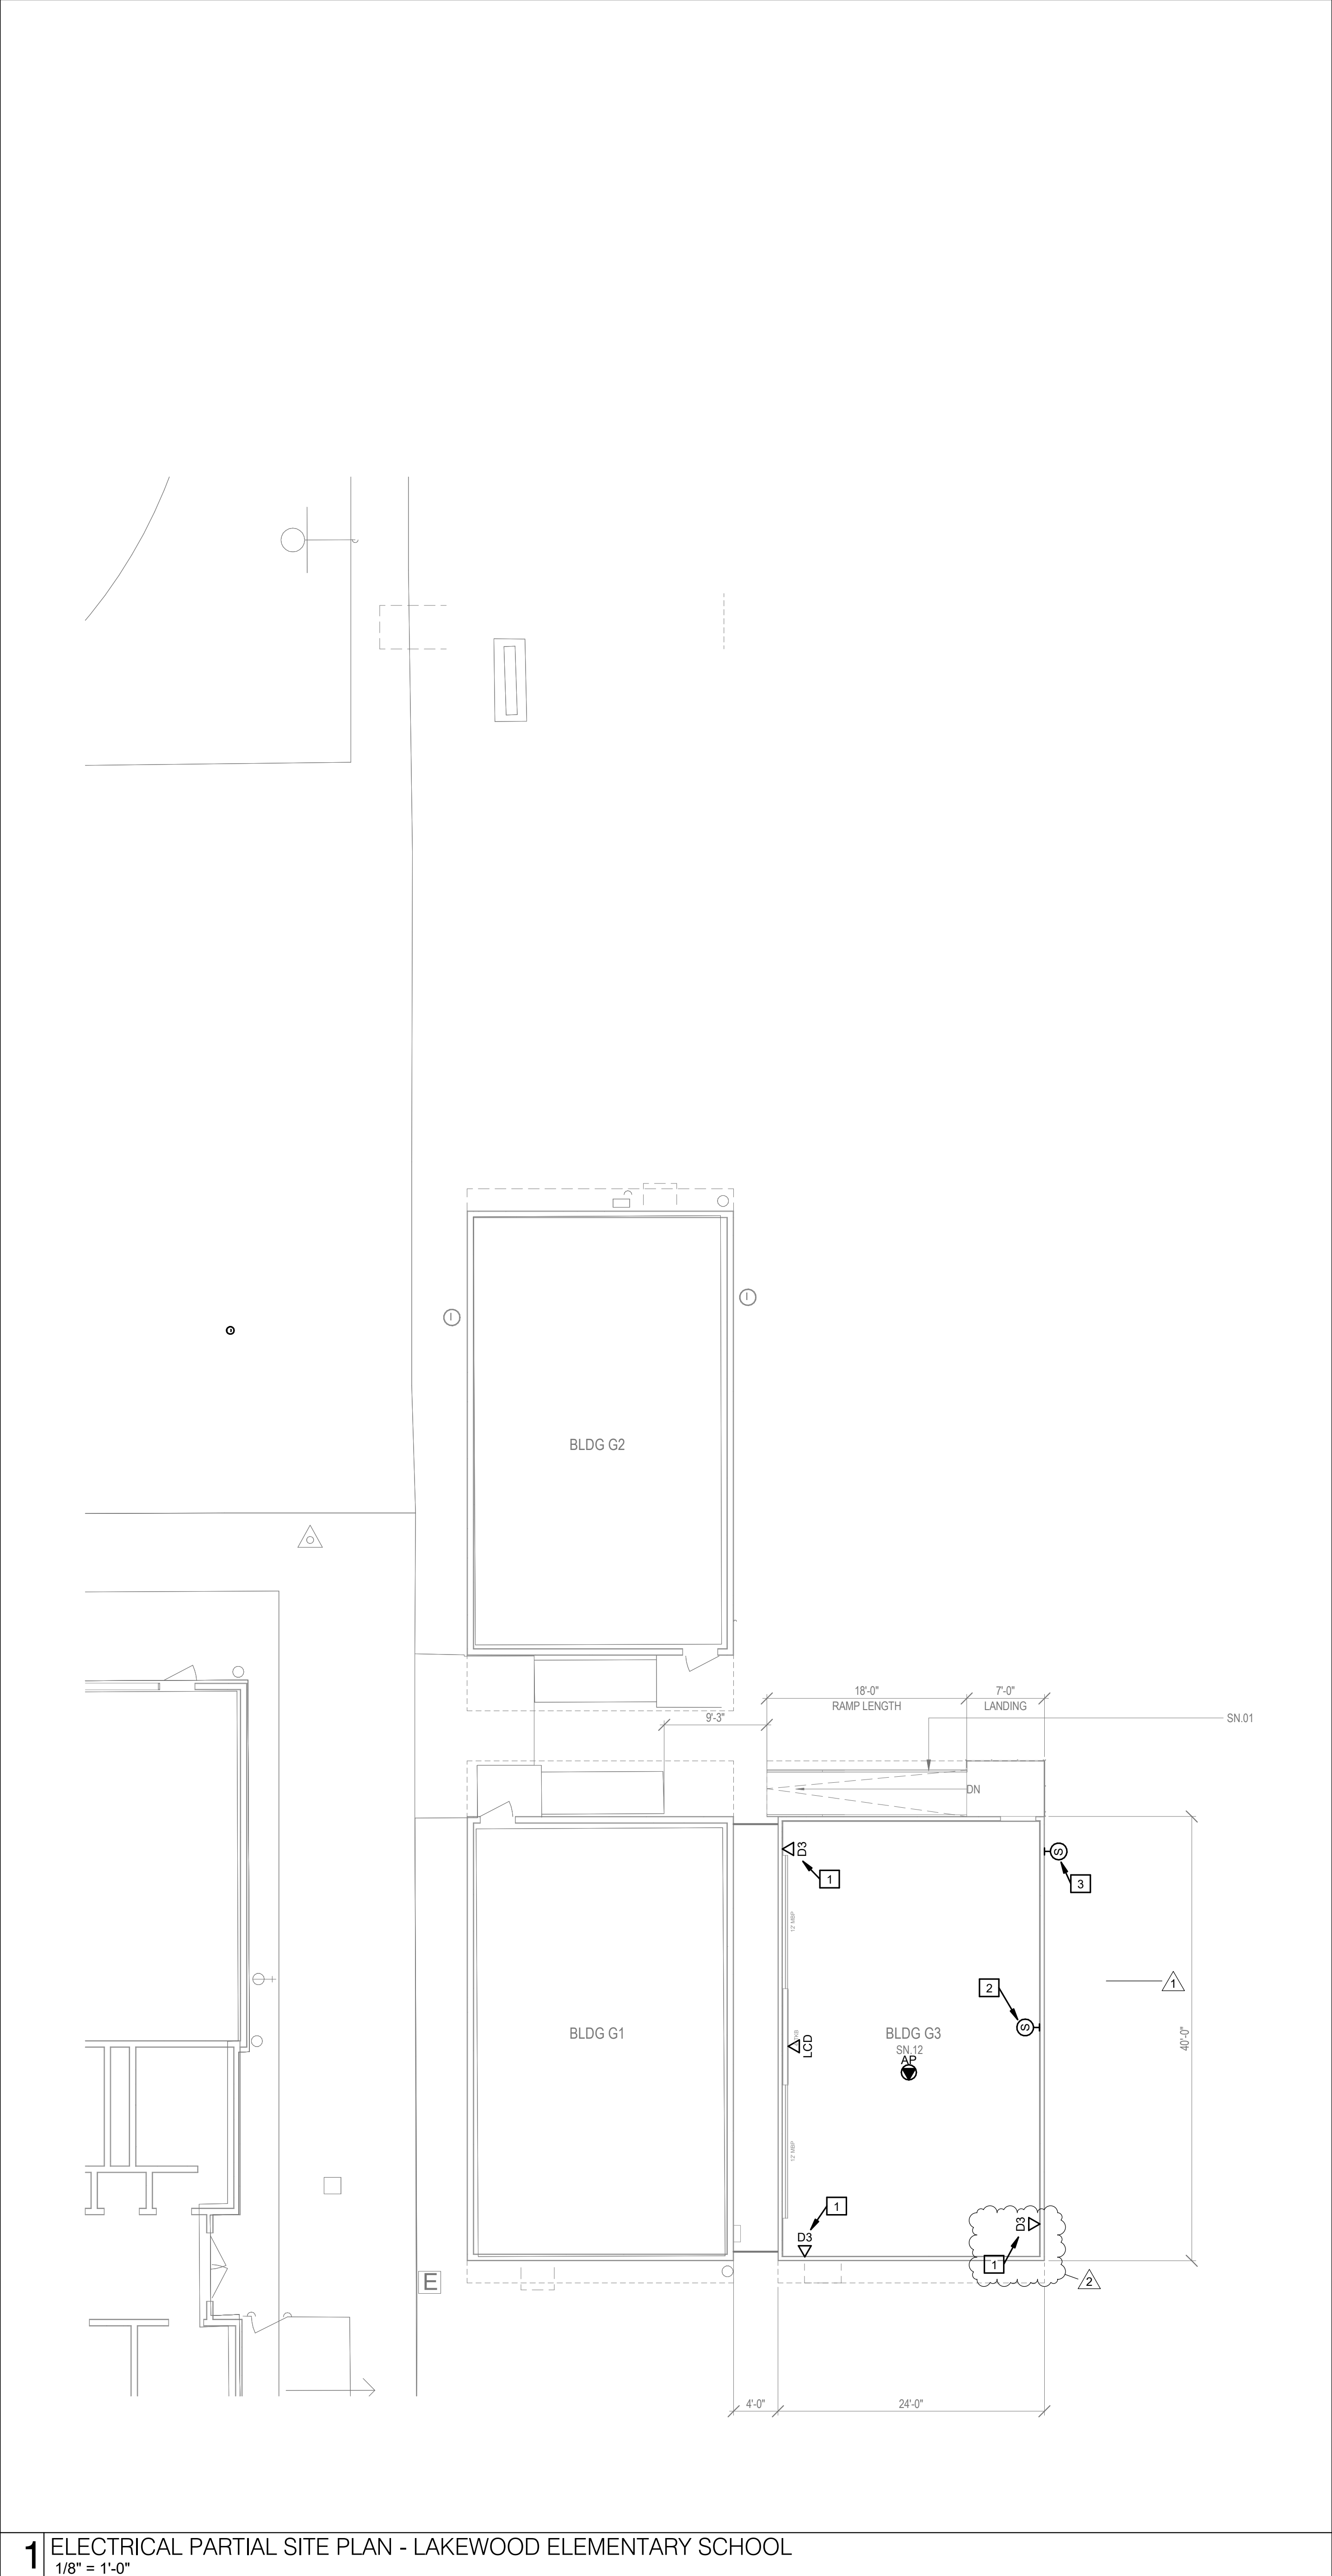

GENERAL NOTES

A. ALL EXTERIOR CAMERAS AND WIRELESS ACCESS POINTS SHALL BE INSTALLED AT 12 FT. A.F.F. UNLESS OTHERWISE NOTED.

B. ALL EXTERIOR CAMERAS AT CANOPY LOCATIONS SHALL BE INSTALLED AT 8 IN. BELOW THE CANOPY. ELECTRICAL CONTRACTOR SHALL VERIFY LOCATIONS PRIOR TO ROUGH-IN OF CONDUIT INFRASTRUCTURE.

C. EXTERIOR PUBLIC ADDRESS SPEAKERS SHALL BE ZONED SEPARATELY FROM INTERIOR PUBLIC ADDRESS SPEAKERS.

D. ACCESS CONTROL CONTRACTOR SHALL CONNECT DOOR HARDWARE CABLE TO ACCESS CONTROL SYSTEM.

E. FOR ALL EXTERIOR MOUNTED IP DEVICES, PROVIDE A BISCUIT TERMINATED ON THE INTERIOR OF THE BUILDING AND A PRETERMINATED CABLE CONNECTED FROM THE BISCUIT TO THE DEVICE.

F. CAMERA ORIENTATION SHOWN DOES NOT INDICATE ACTUAL FIELD OF VIEW. COORDIATE WITH OWNER AND ADJUST CAMERAS FOR PROPER FIELD OF VIEW.

G. EVERY VIDEO DISPLAY (LCD, VIDEO PROJECTOR, ETC.) SHALL RECEIVE 1 QTY. DATA CABLE ROUTED TO NEAREST IDF.

H. ALL CAMERA BACK BOXES MOUNTED UNDER CANOPIES SHALL BE INSTALLED AT 8" BELOW CANOPY BUT NO HIGHER THAN 12 FT. A.F.F.

I. FOR CORNER MOUNTED EXTERIOR CAMERAS, ELECTRICAL CONTRACTOR SHALL ROUTE CONDUIT THROUGH THE CORNER OF THE BUILDING. NO EXPOSED CONDUIT OR SEALTIGHT SHALL BE VISIBLE ON THE EXTERIOR OF THE BUILDING.

J. D1 THROUGH D6 FLOOR POCKETS SHOWN SHALL BE THE SAME FLOOR POCKET SHOWN ON THE ELECTRICAL PLANS. DO NOT PROVIDE A SEPARATE FLOOR POCKET FOR DATA CABLES.

K. PROVIDE NEW TELECOMMUNICATIONS INFRASTRUCTURE SYSTEM PER DISTRICT STANDARDS AND THE SPECIFICATIONS. COORDINATE WITH THE DISTRICT IT REPRESENTATIVE.


L. INTRUSION ALARM SYSTEM TO BE INSTALLED BY THE OWNER'S CONTRACTED VENDOR, PROVIDE CONDUIT PATHWAY TO THE NEW PORTABLE BUILDINGS AND COORDINATE AS REQUIRED.

KEY NOTES

1 AT TYPICAL WORKSTATION, PROVIDE PANDUIT T-70 SURFACE RACEWAY WITH DIVIDER TO ACCESSIBLE CEILING. PROVIDE PANDUIT WORKSTATION OUTLET CENTER OFFSET BOX, T70WC21W. CONNECT POWER RECEPTACLE TO SPARE 20A CIRCUIT AT EXISTING MODULAR BUILDING LOAD CENTER. TELECOM OUTLET WITH 2-BEIGE JACKS AND 1 BLUE JACK (COMPUTER & PHONE).

2 PROVIDE CABLING AND INFRASTRUCTURE FOR OWNER FURNISHED CLOCK/PA SPEAKER.

3 PROVIDE CABLING AND INFRASTRUCTURE FOR OWNER FURNISHED OUTDOOR PA SPEAKER.

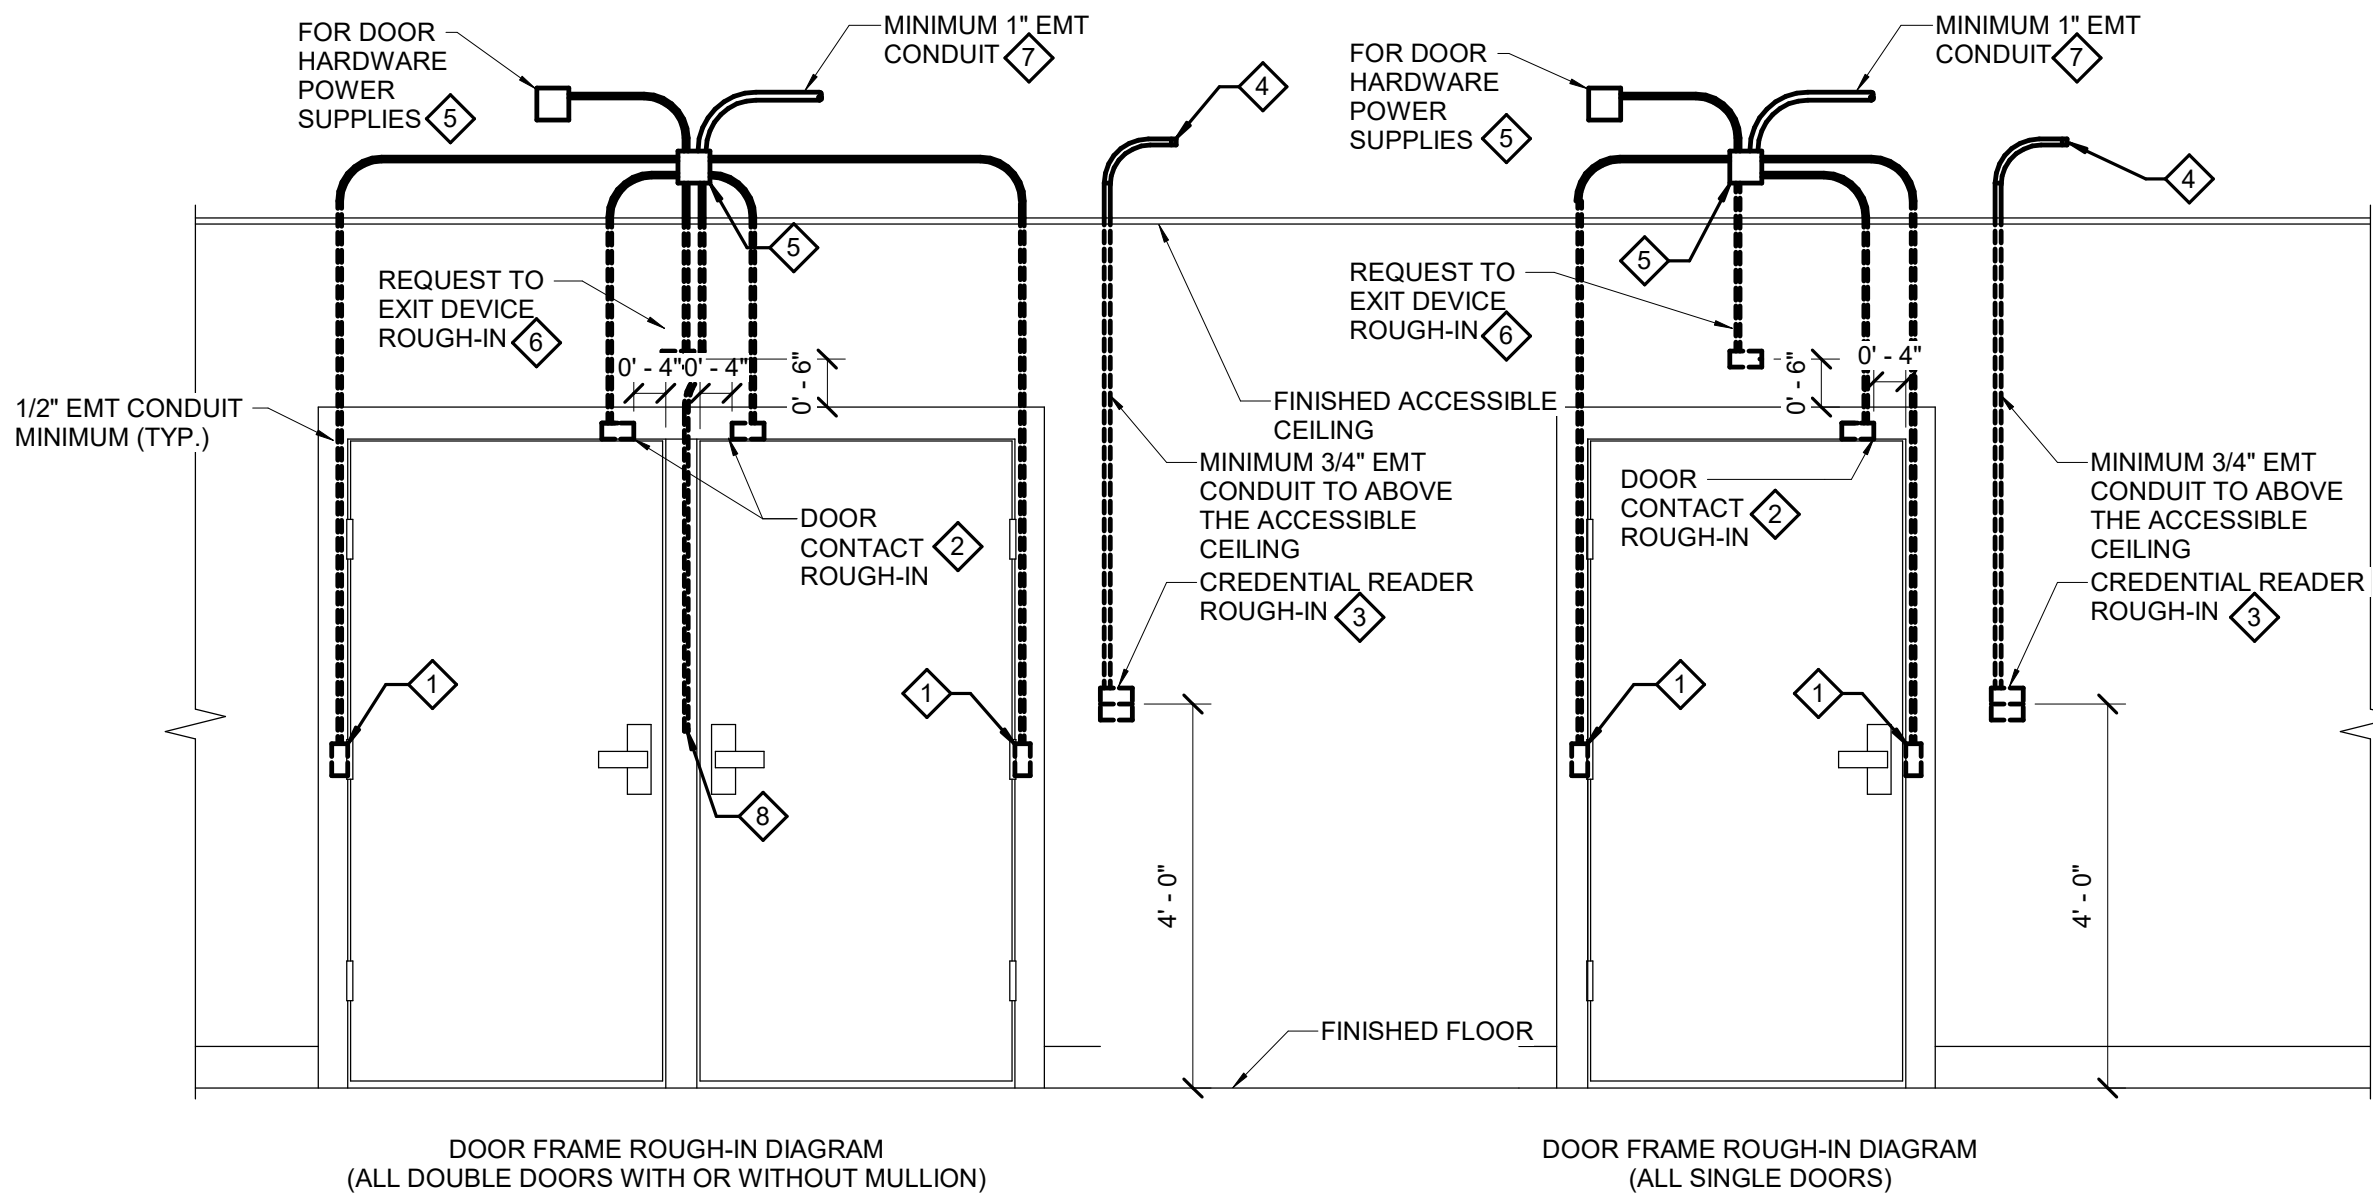


- NOTES:
1. DIMENSIONS SHOWN IN THE DETAIL ABOVE ARE DIAGRAMMATIC. INTENDED TO DESCRIBE THE CONTROLLED SECURITY SCHEME ROUGH-IN REQUIREMENTS OF THE DOORS. DETAILS ABOVE MAY NOT ACCURATELY REPRESENT DOOR SIZE, DOOR SWING, DOOR HARDWARE, OR DOOR FUNCTIONALITY. REFER TO ARCHITECTURAL DOOR HARDWARE SCHEDULE, DOOR HARDWARE GROUPS AND DOOR HARDWARE SPECIFICATIONS FOR FURTHER INFORMATION.
  2. THE DETAIL ABOVE REPRESENTS THE MINIMUM REQUIREMENTS FOR ALL CONTROLLED SECURITY SYSTEM DEVICES AND CABLING UNLESS OTHERWISE NOTED. COORDINATE EXIST REQUIREMENTS WITH SELECTED DOOR MATERIALS, DOOR HARDWARE, AND ACCESSORY HARDWARE AND COMPONENTS AND COORDINATE WITH THE ELECTRICAL CONTRACTOR.
  3. ALL CABLING IN WALLS AND WHERE EXPOSED ON VERTICAL SURFACES SHALL BE INSTALLED IN EMT CONDUIT OR SURFACE MOUNT RACEWAY.
  4. ALL CABLING RUNS VERTICALLY AND HORIZONTALLY ABOVE THE ACCESSIBLE CEILING MAY BE INSTALLED FREE-AIR CABLING PROPERLY RATED FOR THE CEILING ENVIRONMENT.
  5. THE ELECTRICAL OR SECURITY CONTRACTOR SHALL NOT MODIFY ANY FIRE RATED DOOR AND/OR DOOR FRAME. REFER TO THE ARCHITECTURAL SCHEDULE, DETAIL, AND/OR FIRE RATED DOOR SCHEDULE FOR ADDITIONAL INFORMATION. IF THE CONTRACTOR DETERMINES THAT ANY FIRE RATED DOOR AND/OR FRAME WILL REQUIRE A RE-CERTIFICATION OF THE DOOR AND FRAME WITH THE LOCAL AUTHORITY HAVING JURISDICTION (LAJ).
  6. THE ELECTRICAL CONTRACTOR SHALL FURNISH AND INSTALL FIRESTOP MATERIALS FOR ALL CONTROLLED SECURITY DEVICES ROUGH-IN PER PROJECT REQUIREMENTS. REFER TO SPECIFICATIONS FOR ADDITIONAL INFORMATION AND REQUIREMENTS.
  7. REFER TO THE ACCESSORY CABLING WIRING DIAGRAM ON T101 FOR CABLING REQUIREMENTS.
  8. INSTALLATION SHALL INCLUDE ALL POWER REQUIRED FOR SYSTEM OPERATION INCLUDING +120VAC.

- KEYNOTES:
1. PROVIDE JUNCTION BOXES IN THE DOOR FRAME WHEN SHOWN ON THIS DETAIL. ROUGH-IN SHALL BE PROVIDED WHETHER THE CURRENT CODE-RELATED SECURITY DEVICES UTILIZES THEM OR NOT. ALL CONDUITS SHALL BE EMT CONDUIT UNLESS OTHERWISE NOTED. FLEXIBLE CONDUIT OF ANY TYPE WILL NOT BE ACCEPTED. COORDINATE INSTALLATION WITH ON-SITE DOOR FRAME INSTALLATION CONTRACTOR.
  2. ALL DOOR POSITION SWITCHES ARE REQUIRED TO BE RECESSED UNLESS OTHERWISE NOTED. ELECTRIC HINGE MONITORS ARE NOT AN EXCEPTION TO THIS REQUIREMENT FOR THE RECESSED INSTALLATION.
  3. DOUBLE GANG JUNCTION BOX WITH SINGLE GANG PLASTER RING. REFER TO FLOOR PLAN(S) FOR ACTUAL CREDENTIAL READER TYPE AND ROUGH-IN LOCATIONS.
  4. CONDUIT SHALL ROUTE FROM THE CREDENTIAL READER TO THE SECURE SIDE OF THE DOOR. CONDUIT SHALL RUN A MINIMUM OF 12" FROM THE JUNCTION BOX. PROVIDE A NYLON BUSHING ON CONDUIT END.
  5. MOUNT A MINIMUM 4" SQUARE 2-1/8" DEEP JUNCTION BOX WITH BLANK COVER PLATE ON THE SECURE SIDE OF THE DOOR ABOVE ACCESSIBLE TO THE JUNCTION BOX. CONTRACTOR SHALL SIZE THE JUNCTION BOXES PER SYSTEM INSTALLATION REQUIREMENTS AND APPLICABLE CODES. MAINTAIN ACCESS TO THE JUNCTION BOX.
  6. PROVIDE A HORIZONTALLY MOUNTED SINGLE GANG JUNCTION BOX FOR THE REQUEST TO EXIT SENSOR.
  7. CONDUIT SHALL ROUTE TO A MINIMUM OF 12" FROM THE JUNCTION BOX. PROVIDE A NYLON BUSHING ON CONDUIT END.
  8. DO NOT INSTALL IN PERMANENT WALLS ONLY. PROVIDE A NYLON BUSHING ON CONDUIT END. SCHEDULE AND DOOR HARDWARE GROUPS FOR LOCATIONS THAT REQUIRE THIS ROUGH-IN. PROVIDE A NYLON BUSHING ON THE CONDUIT END.

## CONTROLLED SECURITY SCHEME DOOR ROUGH-IN DETAIL

SCALE: NOT TO SCALE


01

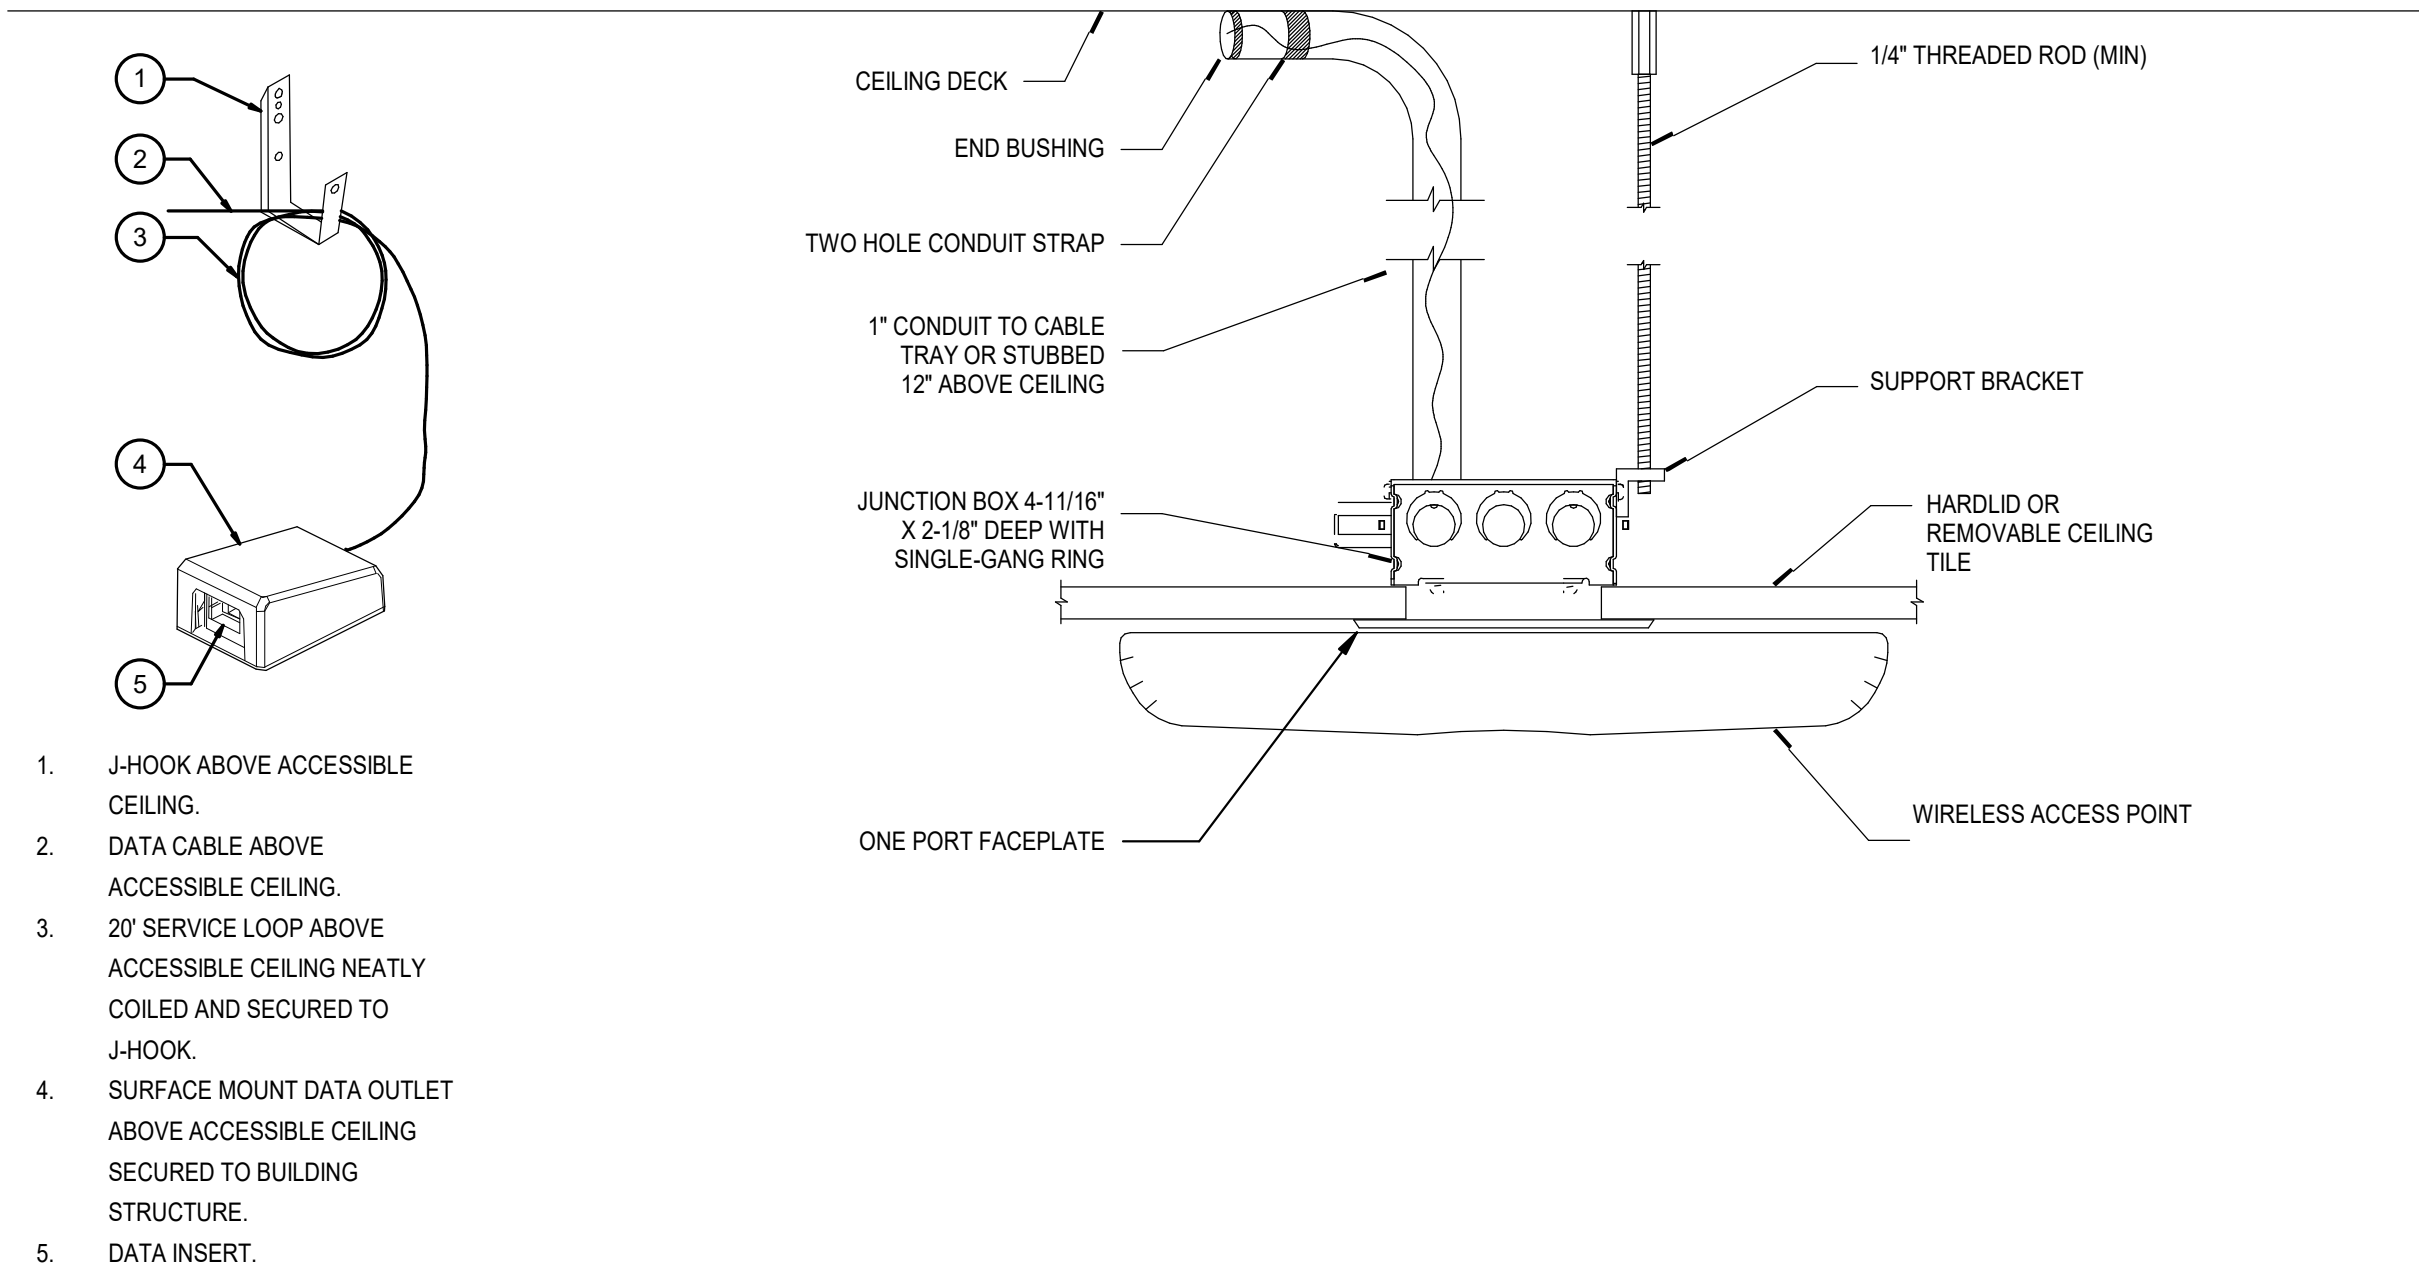

## WIFI CEILING MOUNT

SCALE: NOT TO SCALE

02

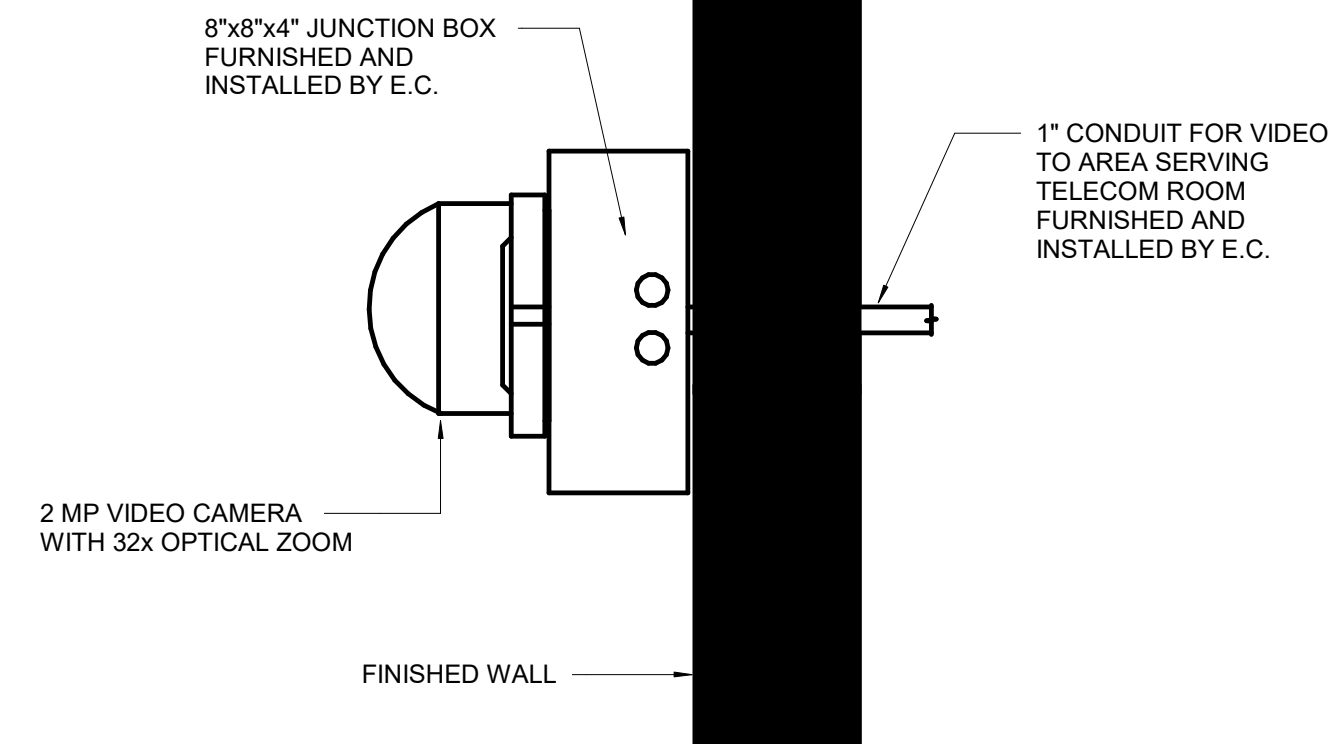

- NOTES:**
1. SECURE 8"x8"x4" WEATHERPROOF JUNCTION BOX TO CMU WALL WITH MINIMUM 1/4" MASONRY FASTENERS. DO NOT ANCHOR TO FACE BRICK.
  2. SECURITY CAMERA SHALL BE MOUNTED DIRECTLY TO THE 8"x8"x4" EXTERIOR JUNCTION BOX. ROUTE ALL CAMERA CABLEING THROUGH JUNCTION BOX WITH CONDUIT CONNECTIONS AS REQUIRED.
  3. SEAL JUNCTION BOX AND MOUNTING PENETRATIONS AT EXTERIOR WALL TO PREVENT WATER INFILTRATION.
  4. REFER TO SECURITY CAMERA REQUIREMENTS SCHEDULE ON SHEET 2.01 FOR CAMERA TYPE 4 AND ADDITIONAL INSTALLATION REQUIREMENTS.

## EXTERIOR CAMERA - WALL MOUNT

SCALE: N.T.S.

03



LODI UNIFIED SCHOOL DISTRICT  
LAKEWOOD ELEMENTARY SCHOOL  
1100 N HAM LANE  
LODI, CA 95242

**DSA SUBMITTAL**

FOLSOM, CA 916-355-9922 [www.pbk.com](http://www.pbk.com)



| CLIENT<br>LODI USD  |                          |      |
|---------------------|--------------------------|------|
| DATE<br>03/20/2026  | PROJECT NUMBER<br>250048 |      |
| DRAWING HISTORY     |                          |      |
| No.                 | Description              | Date |
| 2                   | ADDENDUM 02              |      |
|                     |                          |      |
|                     |                          |      |
|                     |                          |      |
|                     |                          |      |
| CHECKED BY: Checker |                          |      |
| DRAWN BY: Author    |                          |      |

## TECHNOLOGY DETAILS

# T601