


BURNHAM SCHOOL BRIDGEWATER

C. J. LAWLER ASSOCIATES
ARCHITECTS & PLANNERS
7 SOUTH MAIN STREET WEST HARTFORD, CT. 06107 (203) 223-6126

BURTON & VANHOUGH ENGINEERS INC.
10 NORTH MAIN STREET WEST HARTFORD, CT. 06107 (203) 223-6126
GIRARD & CO. ENGINEERS
40 WATERBURY AVENUE HARTFORD, CT. 06107 (203) 223-6126

FIRST FLOOR HVAC PLAN

H-3

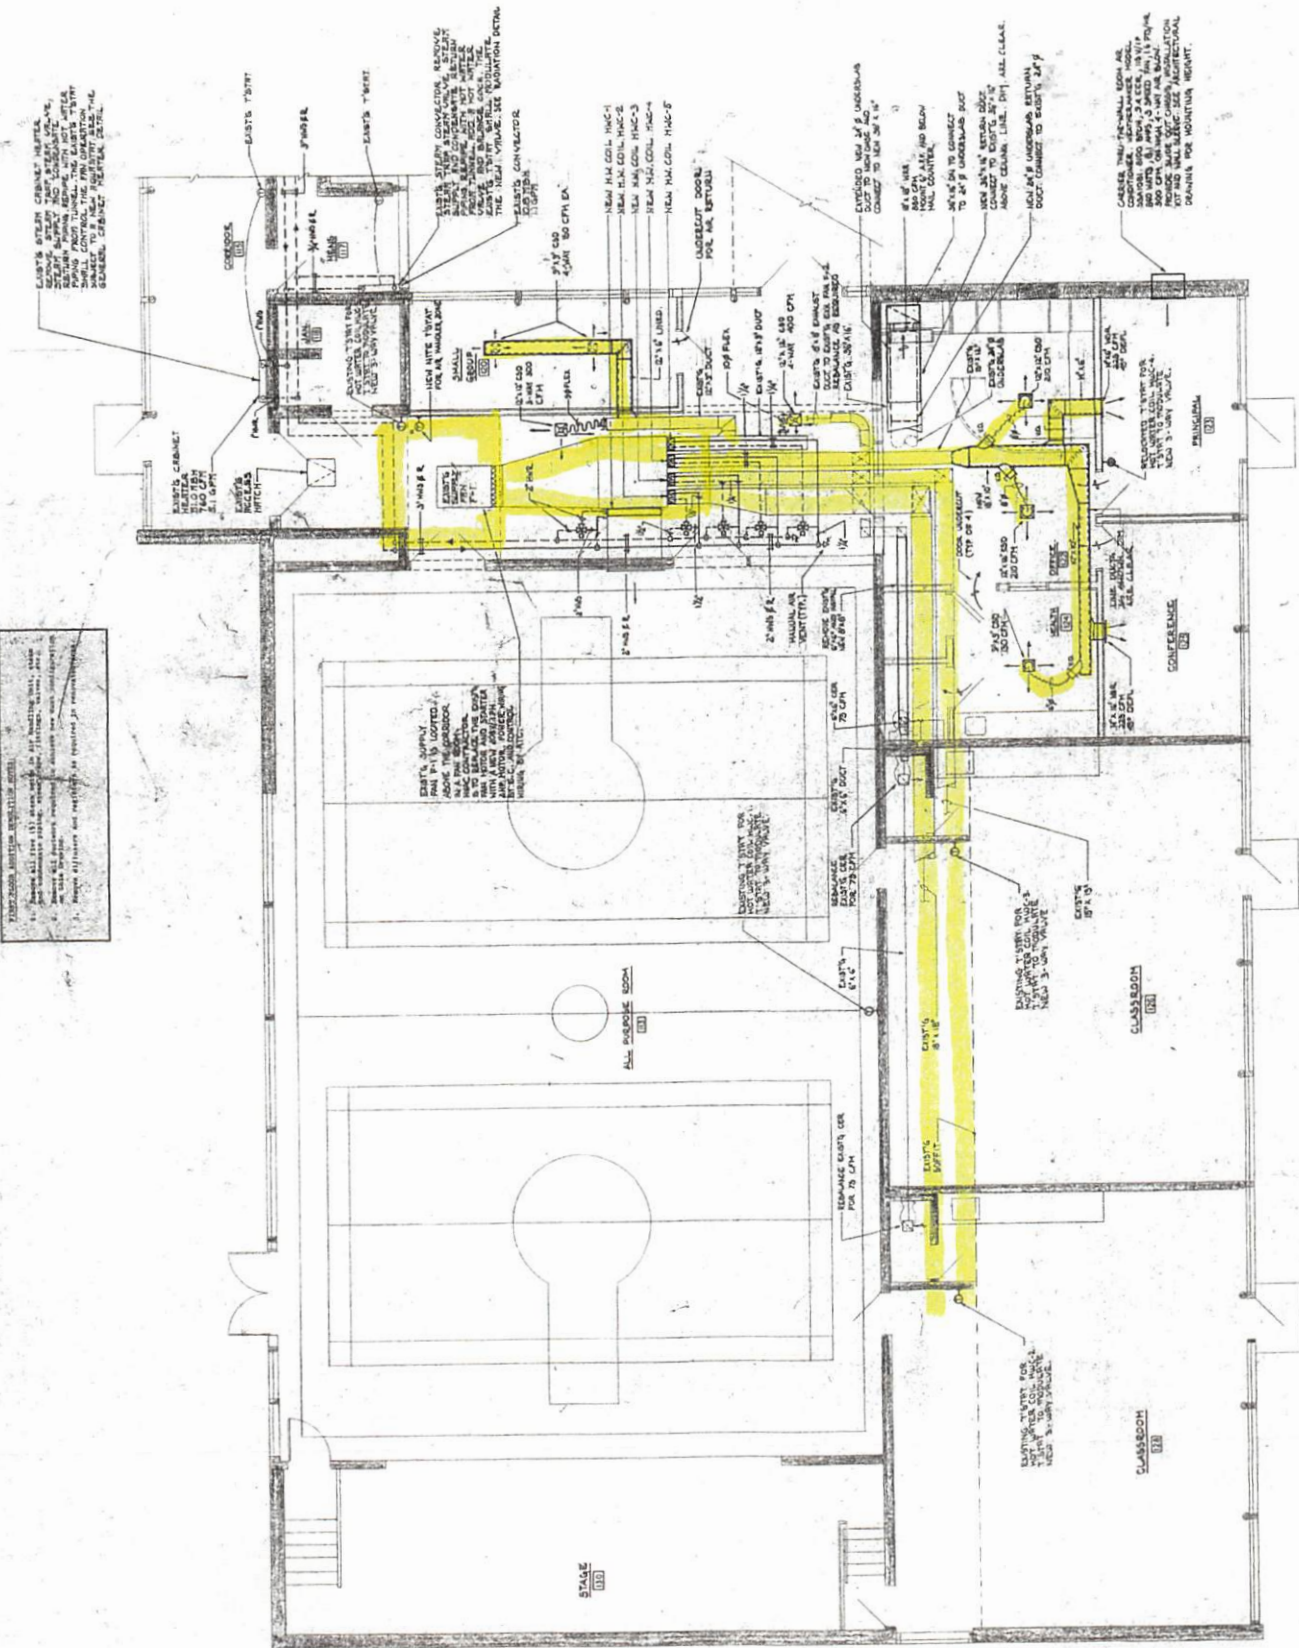

FIRST FLOOR HVAC PLAN
SCALE: 1/4" = 1'-0"