


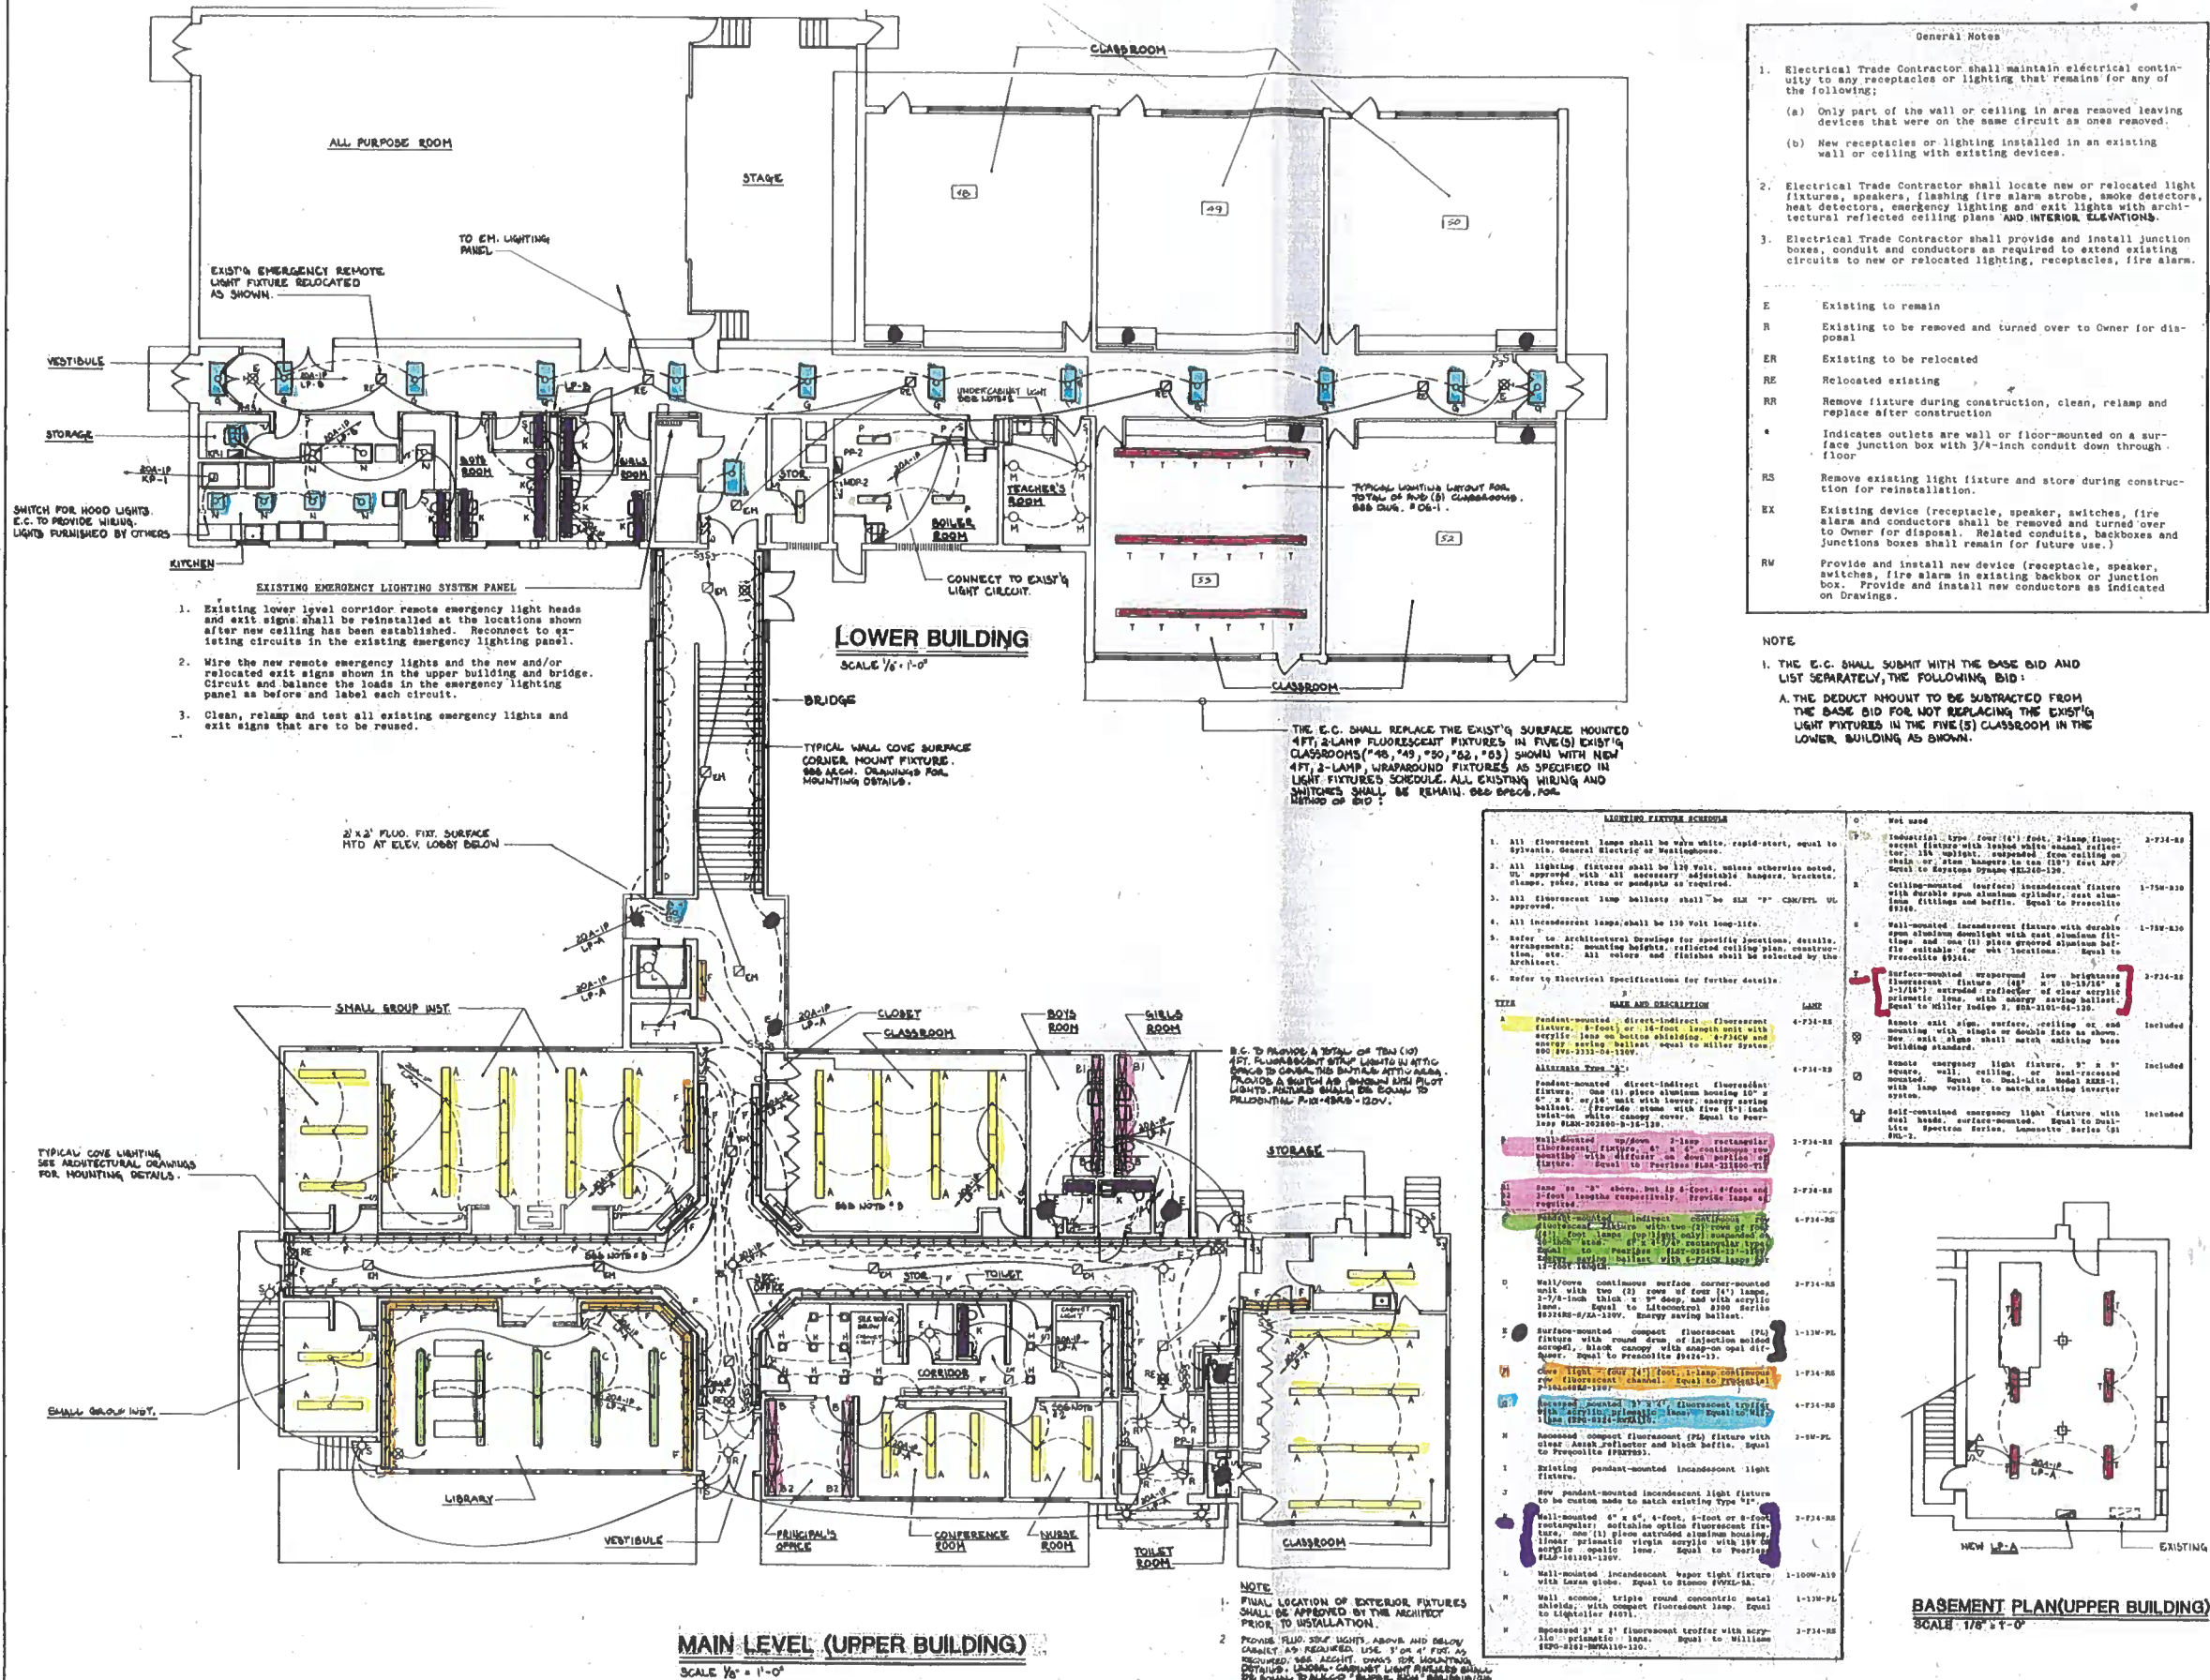



C. J. LAWLER ASSOCIATES
ARCHITECTS & PLANNERS

7 ADAMS STREET, NEW HAVEN, CT 06510 (203) 338-8888

BURTON & VANHOUGH ENGINEERS, INC.
1000 Main Street, New Haven, CT 06510 (203) 338-8888

STANDARD & CO. ENGINEERS
1000 Main Street, New Haven, CT 06510 (203) 338-8888

ELECTRICAL FLOOR PLAN-LIGHTING

SCALE 1/8" = 1'-0"

DATE 3-1-88

BY J. L.

APP'D J. L.

E-1

BOOTH FREE SCHOOL ROXBURY