


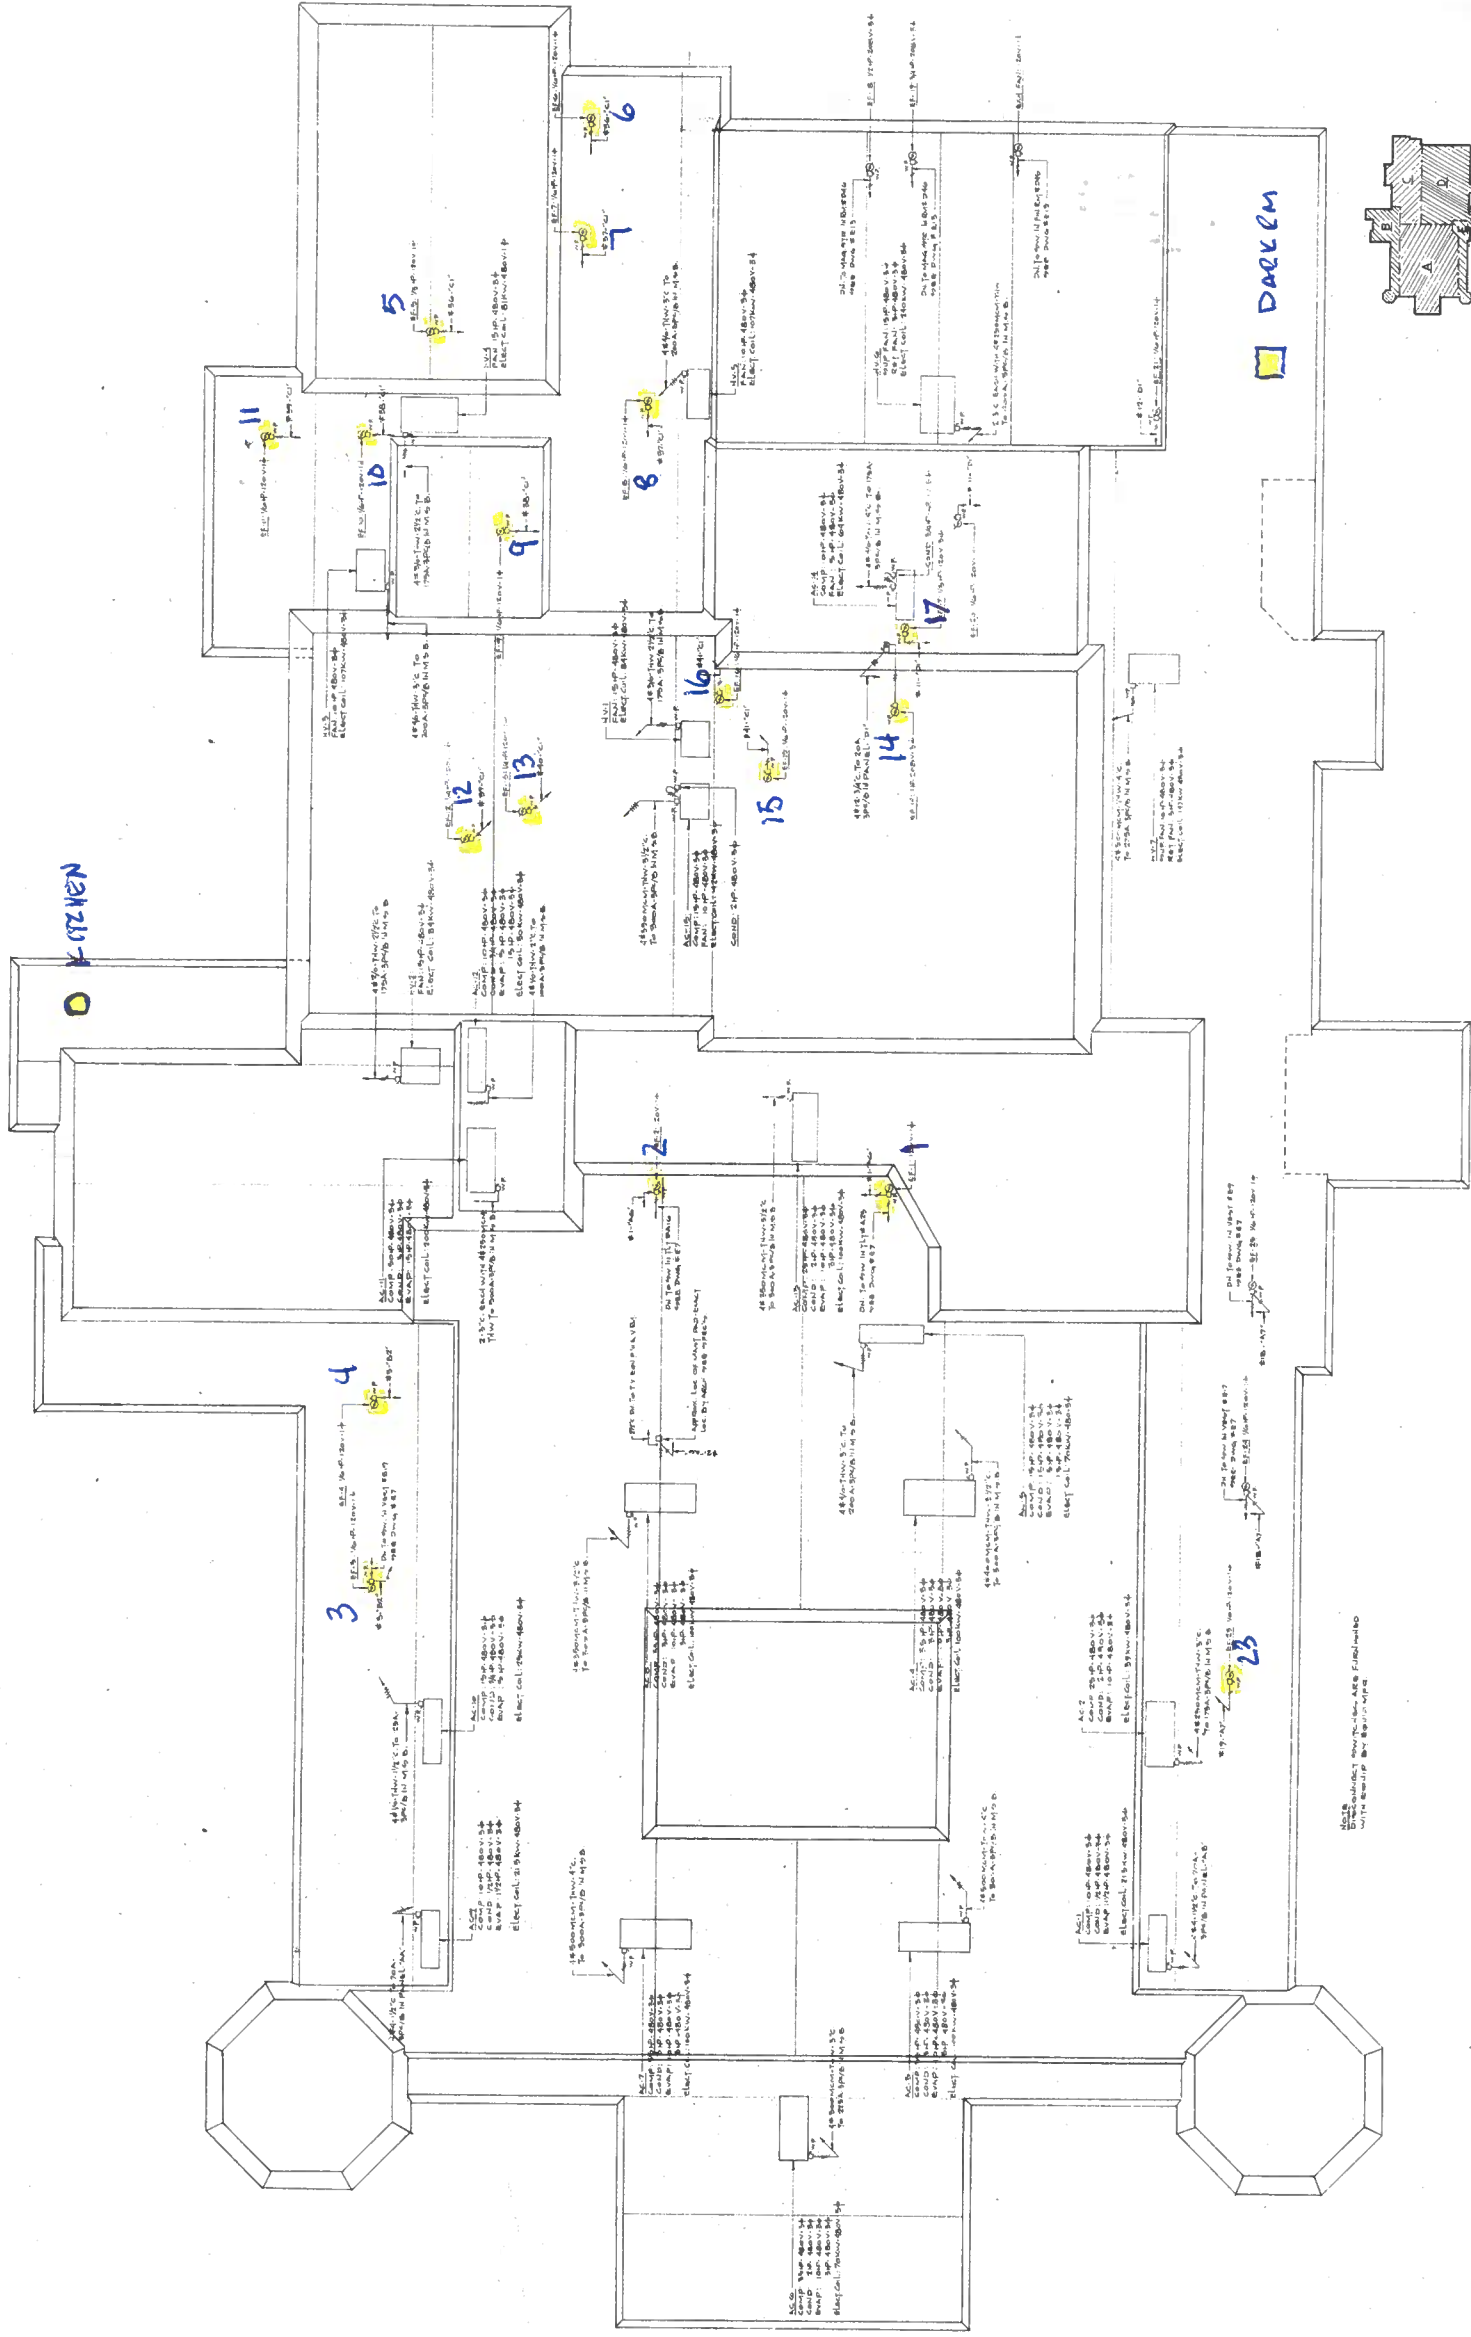

ELECTRICAL ROOF PLAN

ELECTRICAL ROOF PLAN
 THE PARTNERSHIP OF LYONS - MATHER - LECHNER Architects
 BRIDGEPORT CONNECTICUT

NOTES:
 1. ALL ELECTRICAL WORK SHALL BE IN ACCORDANCE WITH THE NATIONAL ELECTRICAL CODE (NEC) AND THE CONNECTICUT ELECTRICAL CODE (C.E.C.).
 2. ALL ELECTRICAL WORK SHALL BE IN ACCORDANCE WITH THE NATIONAL FIRE PROTECTION ASSOCIATION (NFPA) 70-1999.

DATE: 10/10/00
 DRAWN BY: J. LYONS
 CHECKED BY: J. MATHER
 APPROVED BY: J. LECHNER

E-10