

Addendum No.: 3

Date Of Addendum: 4/15/2026

**Underground Storage Tank Replacement at Harwinton Consolidated School
115 Litchfield Road, Harwinton, CT 06791
State Project 210-0037CVOT**

Original Bid Due Date / Time:

4/21/2026

12:00PM

Previous Addendums: Addendum 1,2

TO: Prospective Bid Proposers:

This Addendum forms part of the "Contract Documents" and modifies or clarifies the original "Contract Documents" for this Project dated 6/9/2025. Prospective Bid Proposers shall acknowledge receipt of the total number the Addenda issued for this Project on the space provided on Section 00 21 13 Bid Form.

Failure to acknowledge receipt of the total number the Addenda issued for this Project on the space provided on Section 00 21 13 Bid Form shall subject Bid Proposers to disqualification.

The following clarifications are applicable to drawings and specifications for the project referenced above.


Item 1:

Correction to Addendum 2, Item 4:

Scope Change: Due to extended lead times, RSD-10 intends to purchase the alternate bid daytank with return pumpset, as well as the replacement duplex boiler pump set from Pryco prior to issuing a contract with the selected contractor. Attached are the quotes from Pryco indicating parts included with this equipment (these attachments are the same as Addendum 2). Installation, startup will be by the Contractor. Contractor to provide 4" housekeeping pad for new daytank.

See updated drawings M-101, M-501 and M-502.

End of Addendum 3

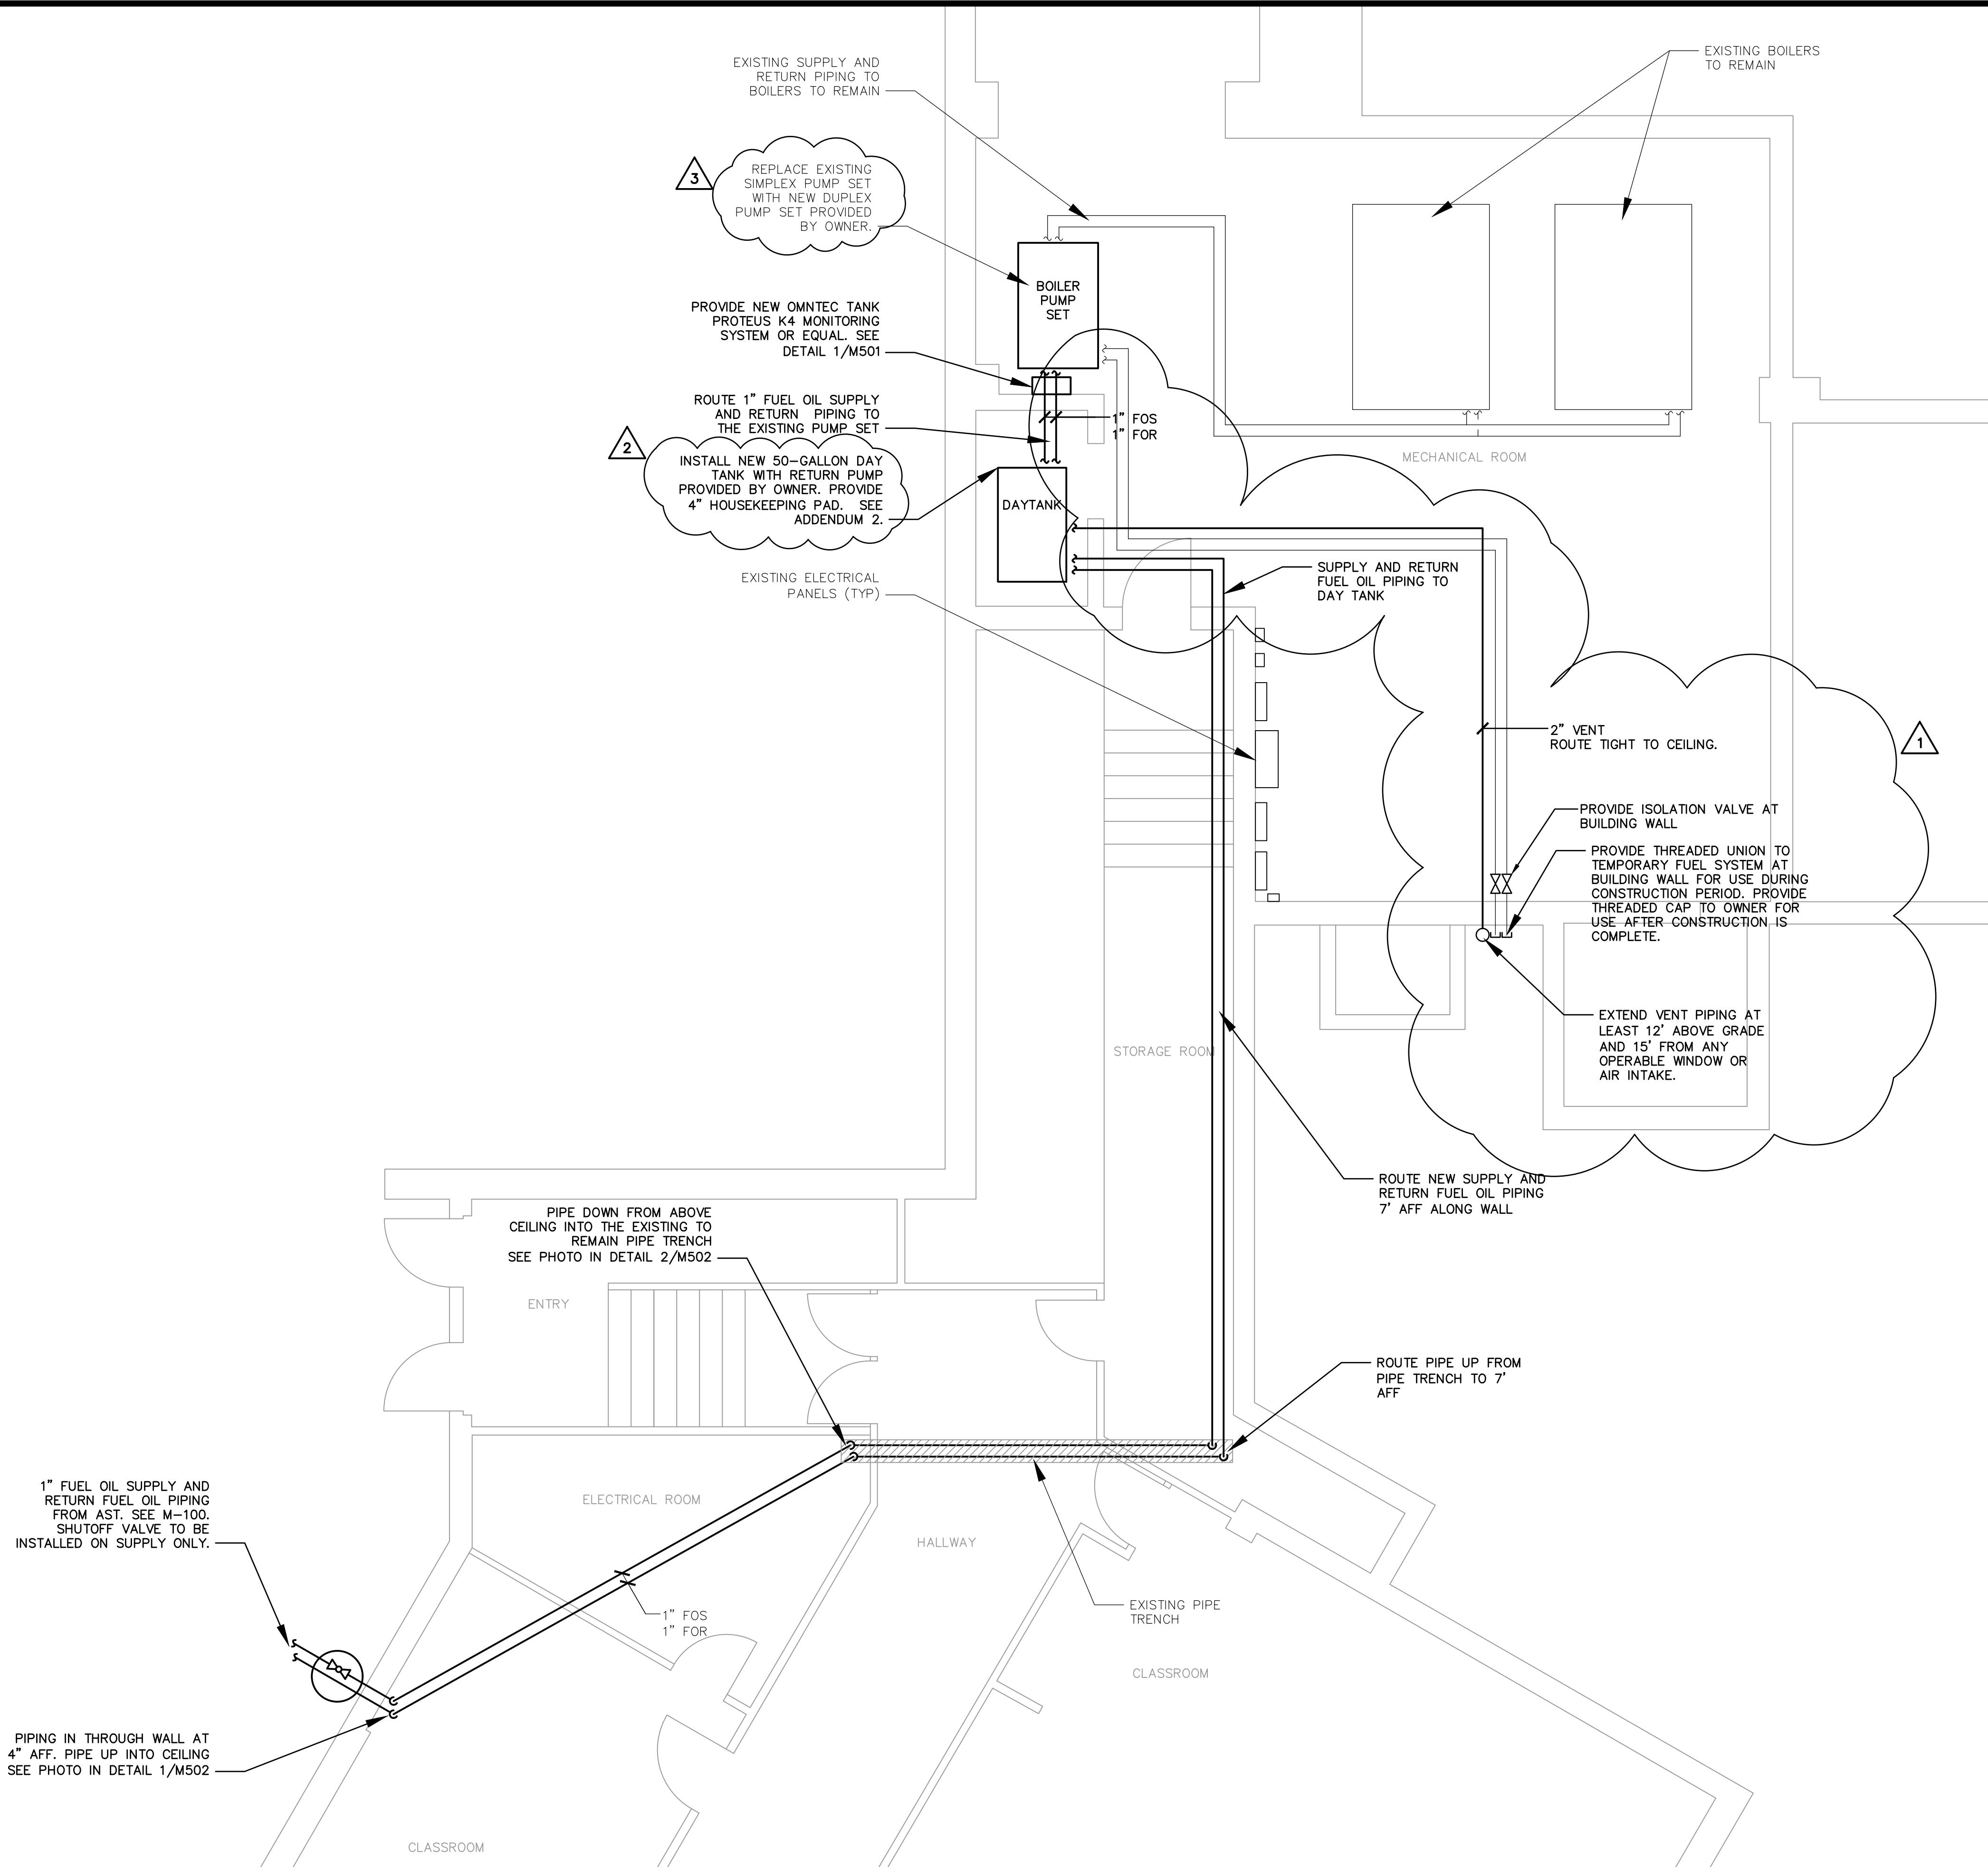

1 FIRST FLOOR NEW WORK PLAN
SCALE: 1/4" = 1'-0"

1 KEY PLAN
NOT TO SCALE

LINETYPE LEGEND	
	EXISTING TO REMAIN
	DEMOLITION
	NEW WORK

REGIONAL SCHOOL DISTRICT 10
MECHANICAL FIRST FLOOR
NEW WORK PLAN
HARWINTON CONSOLIDATED SCHOOL
UST REPLACEMENT

HARWINTONCONNECTICUT

PROJ. No.: 20241534.A11
DATE: 06/9/2025

M-101


SCALE:
HORIZ.: 1/4" = 1'-0"
VERT.:
DATUM:
HORIZ.:
VERT.:
GRAPHIC SCALE
0' 2' 4' 8'

FUSS & O'NEILL
ONE FINANCIAL PLAZA, 15th FLOOR
HARTFORD, CT 06103
860.445.2468
www.foss.com


No.	DATE	DESCRIPTION	DESIGNER	REVIEWER
1	4/10/2026	ADDENDUM 1	J.T	J.T
2	4/15/2026	ADDENDUM 2	J.T	J.T
3	4/15/2026	ADDENDUM 3	J.T	J.T

File: J:\DWG\2024\1534\A11MEP\Mechanical\2024\1534.A11_M501.dwg Layout: M-501 Plotted: 2026-04-15 3:48 PM Saved: 2025-06-10 2:08 PM User: Caitlin Abel
MS VIEW: LAYER STATE: PC3: NONE STR/CTB: FO STB


3 CONVAULT 6,000 GALLON ABOVEGROUND STORAGE TANK
SCALE: NTS

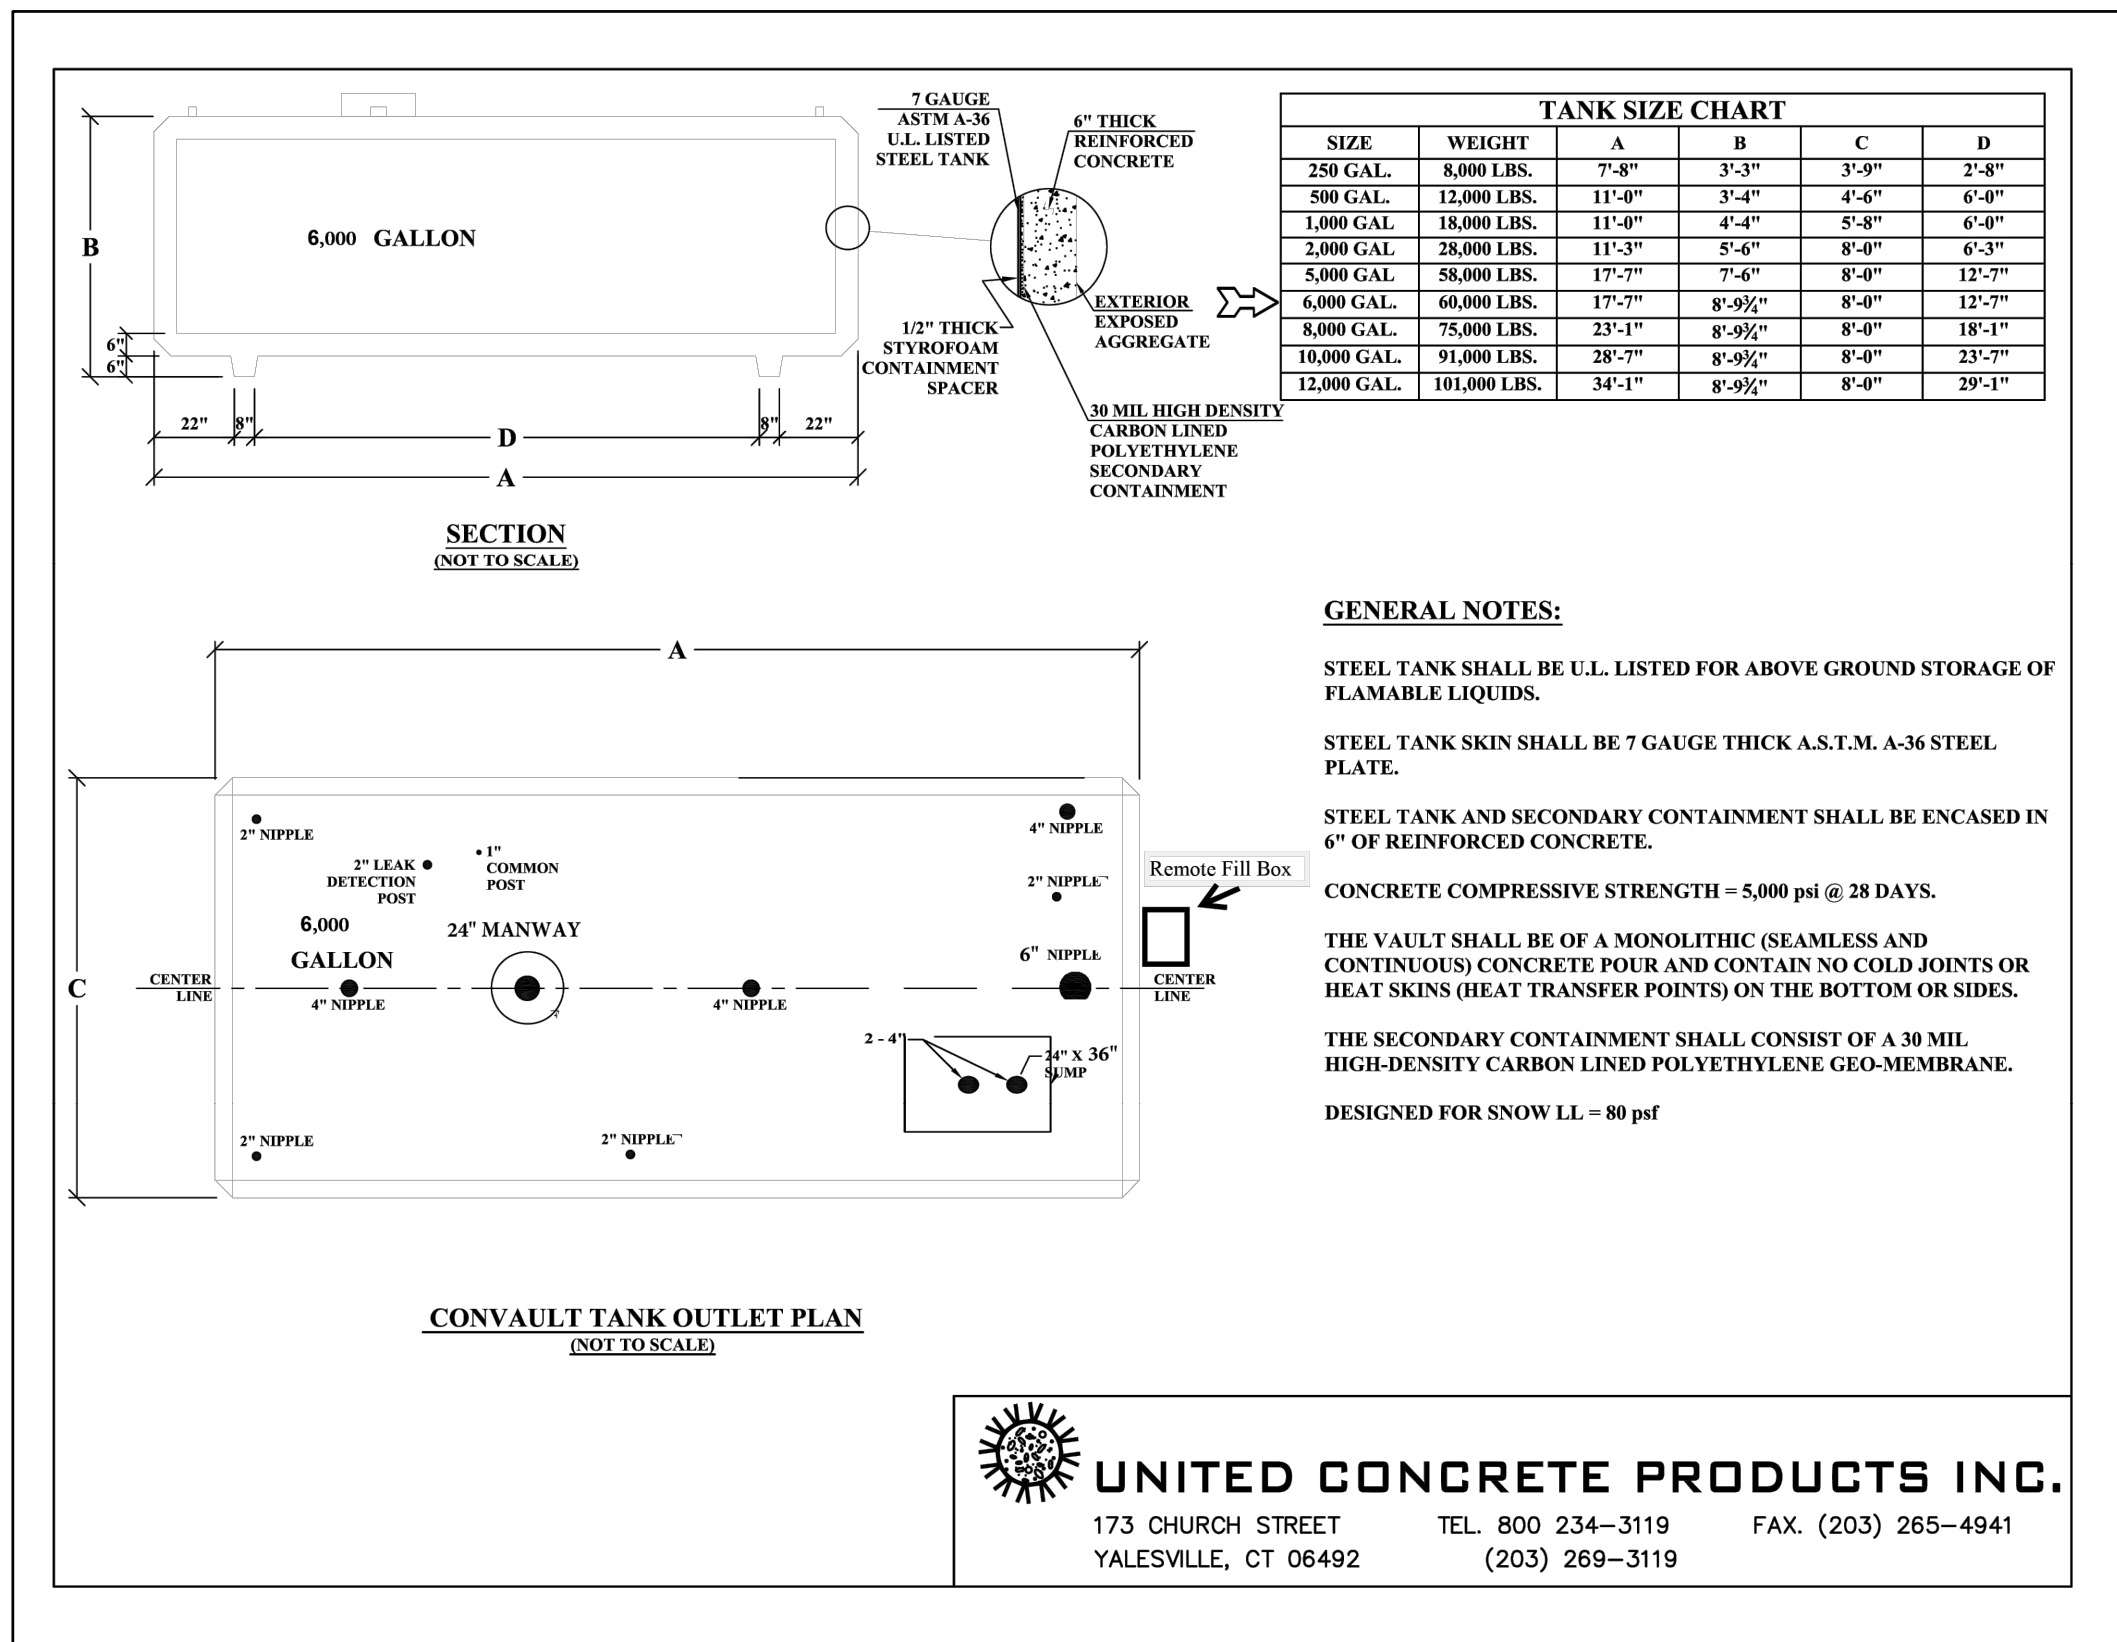


2 SUMP DETAIL
SCALE: NTS

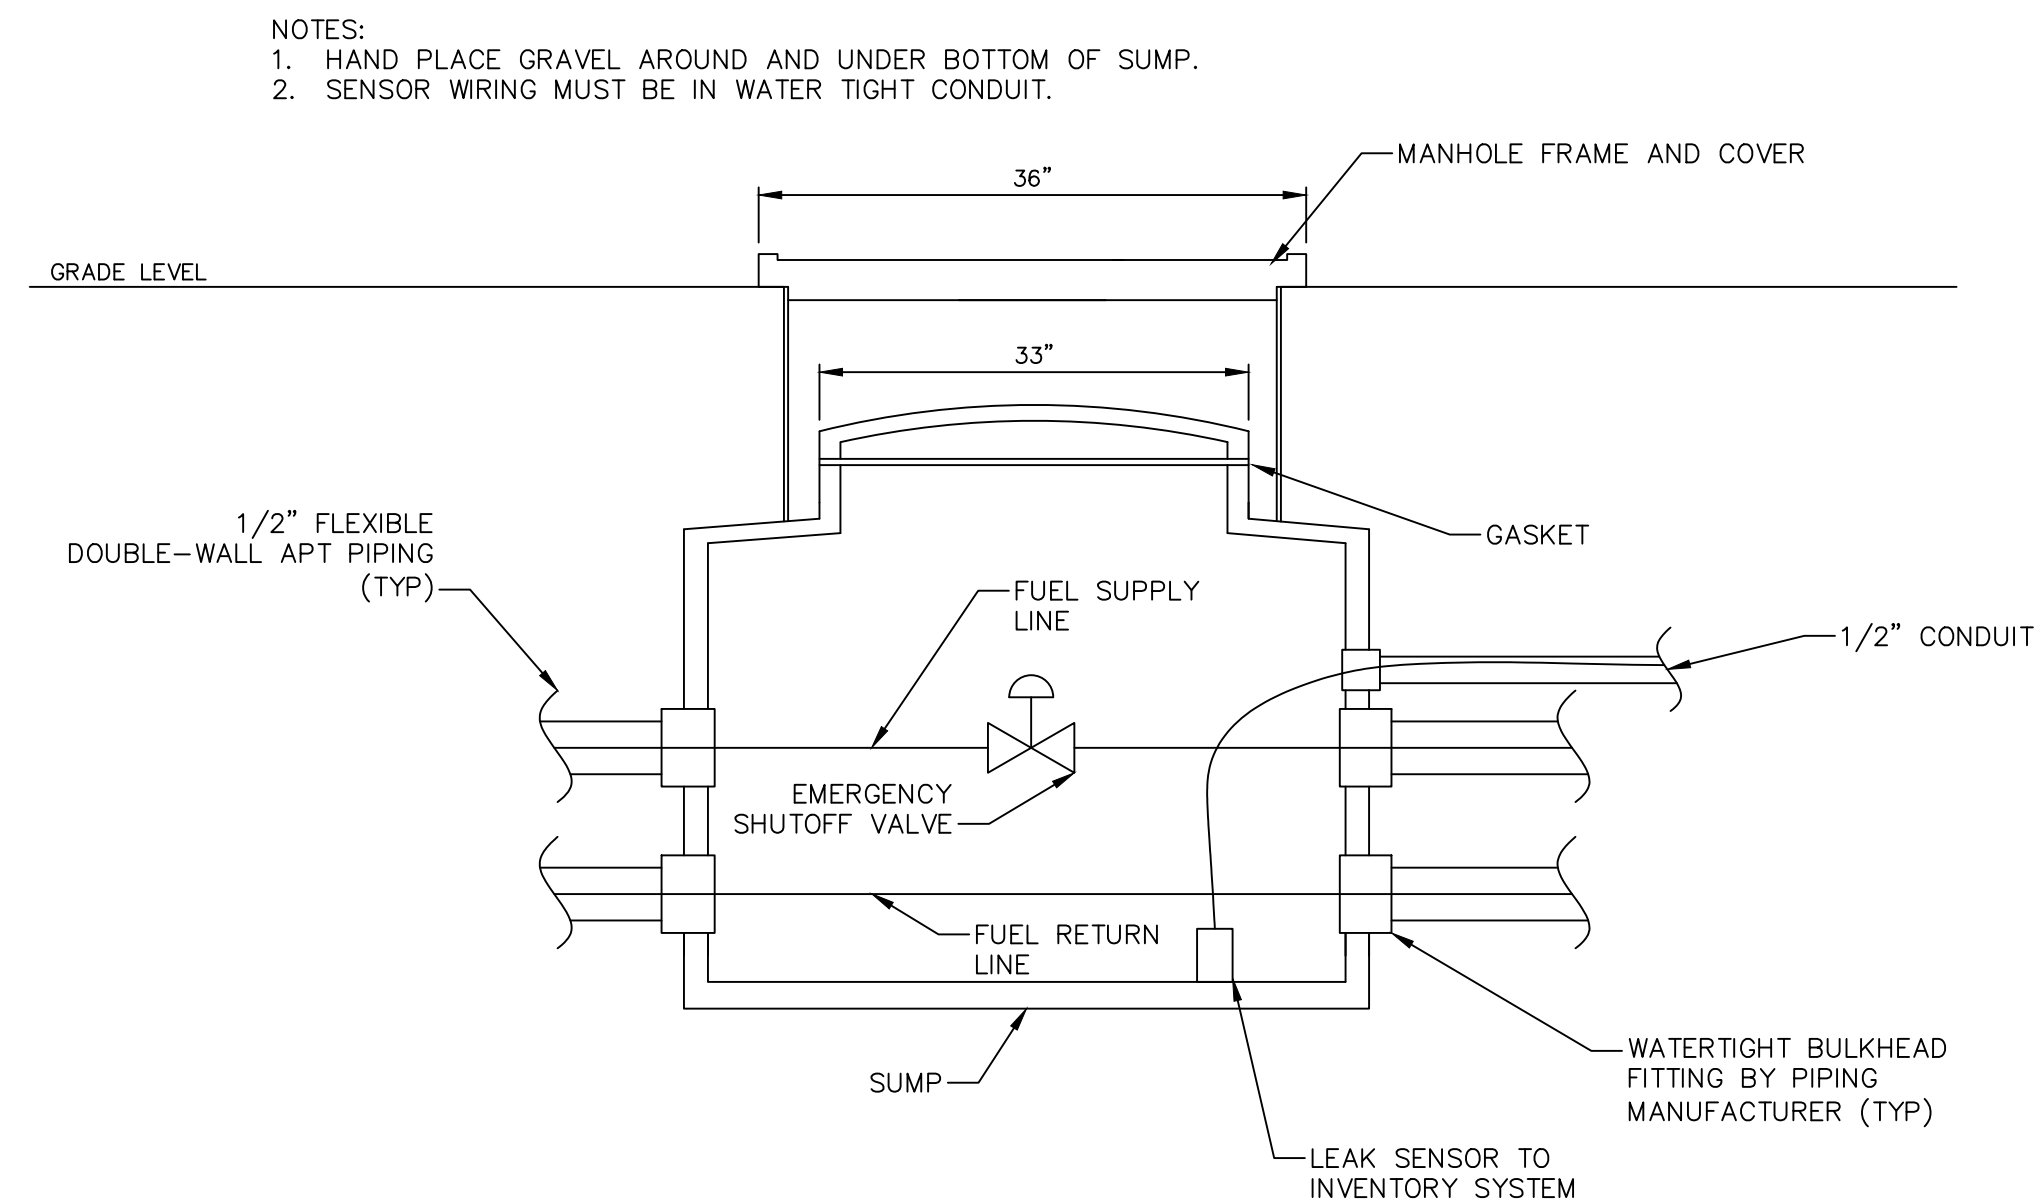

1 AST PIPING AND CONTROLS SCHEMATIC DIAGRAM
SCALE: NTS

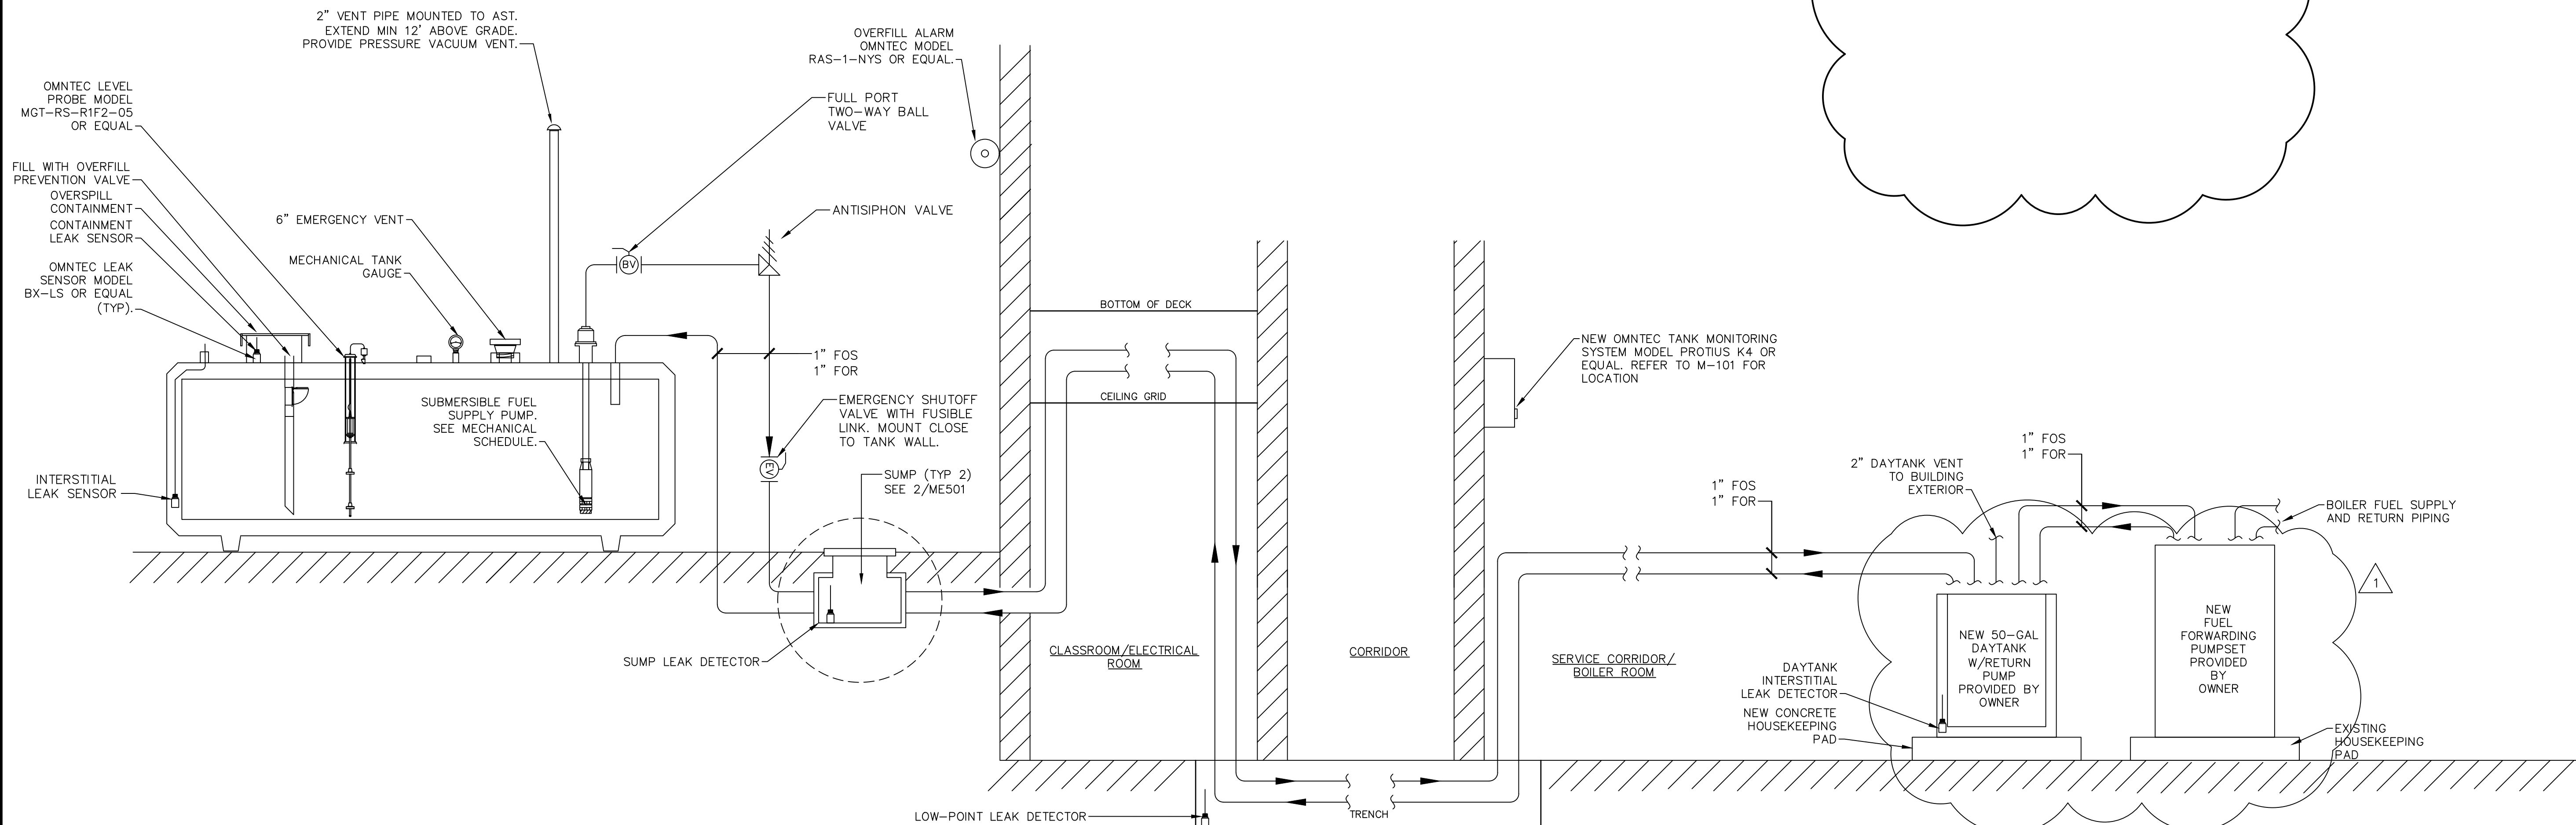

REGIONAL SCHOOL DISTRICT 10		CONNECTICUT	
MECHANICAL DETAILS		HARWINTON CONSOLIDATED SCHOOL	
HARWINTON		UST REPLACEMENT	
FUSSE & O'NEILL		ONE FINANCIAL PLAZA, 15th FLOOR HARTFORD, CT 06103 860.466.2468 www.fosse.com	
PROJECT No.: 20241534.A11		DATE: 06/9/2025	
M-501		DESIGNER REVIEWER	
DATE		DESCRIPTION	
3 4/15/2026		ADDENDUM 3	
No.		JLT	

 

4 SEQUENCE OF OPERATIONS
SCALE: NTS

NOTES:
1.
2. ALTERNATE BID: PROVIDE MOTOR STARTER FOR SUPPLY AND RETURN PUMPS. 60 MESH FUEL STRAINER, NEMA 1 PUMP SET ENCLOSURE, CHECK VALVE, MANUAL CUT-OFF BALL VALVE FOR PUMP ISOLATION, FUEL DETECTION SWITCH, EXTERNAL PRESSURE RELIEF BYPASS VALVE, DUPLEX ALTERNATOR TRANSFER SWITCH.