



Date: May 18, 2026

Project: San Angelo ISD Paging Upgrade (RFP #26-008)

Subject: Addendum 01

05/18/26

TECHNOLOGY ITEMS FOR ADDENDUM 01

NOTICE TO PROPOSERS:

- A. This Addendum shall be considered part of the contract documents for the above-mentioned project as though it had been issued at the same time and incorporated integrally therewith. Where provisions of the following supplementary data differ from those of the original contract documents, this Addendum shall govern and take precedence.
- B. Proposers are hereby notified that they shall make any necessary adjustments in their estimate on account of this Addendum. It will be construed that each Proposer's proposal is submitted with full knowledge of all modifications and supplemental data specified therein. Acknowledge receipt of this addendum in the space provided on the proposal form. Failure to do so may subject Proposer to disqualification.

REFERENCE IS MADE TO THE BIDDING RFIS, DRAWINGS AND THE PROJECT MANUAL AS NOTED:

CLARIFICATIONS:

Question 1: Will San Angelo ISD consider substitutions to Valcom?

Answer 1: San Angelo Independent School District requires a single PA/Bell/Clock system across all district sites, which includes campuses outside the scope of this project. Therefore, for consistency the paging system will remain Valcom, as specified.

Question 2: Who does the district source ceiling tiles from?

Answer 2: Ceiling tiles are locally available at Lowe's.

Question 3: Is there a reason why some [speakers] are grey and some are black?

Answer 3: Contractor shall remove speakers and associated cabling for all speaker locations shown in halftone unless noted otherwise. Refer to addendum 01 drawings and keynotes. Refer also to matrix on TG101 for summary of scope intent by location.

Question 4: T117: in TC2, notes a new proposed TC. Do we submit pricing as an option? Will we need to include new fiber cable? If so, what strand count? OM3/4/5, or OS2? Do we include a wall mount, 2-post, or 4-post rack? Do we route any existing cables to new proposed TC or just the new cables for the PAS?

Answer 4: The new TC is not in scope for this project. The new TC will be built under another contract that occurs after the paging upgrade will be completed. New cabling in this project will route to nearest existing TC. Refer to addendum 01.

www.cruxsolutions.com

817-852-6689

Question 5: T124: bottom left of drawing, notes Belaire ES – Add Alternate 2. Is this a typo and not part of alternate 2?

Answer 5: Belaire ES is basebid. It is not an alternate. Refer to addendum 01.

PROJECT MANUAL:

ADD No 1, Tech. Item 1: **To the Section 09 5113, "ACOUSTIC PANEL CEILINGS,"**

- 1) Added to 2.2-A-16-d acceptable ceiling tile make/manufacturer.

DRAWINGS:

ADD No 1, Tech. Item 2: **To the Drawings, Sheet TG101, "GENERAL NOTES AND SYMBOLS,"**

- 1) Added AVR audio/video rack to "Audio Visual Symbols Legend" and reduced description on other listed AV components.
- 2) Adjusted placement/size of "Paging Matrix" and "Public Address System And Clock Symbols Legend", no content changed.

ADD No 1, Tech. Item 3: **To the Drawings, Sheet T101, "FLOOR PLAN - CENTRAL HS - BUILDING A - TUCKER,"**

- 1) Added halftone speaker clarification to Sheet Notes.
- 2) Added paint/finish clarification to Sheet Notes.
- 3) Clarified high-ceiling lift requirement item in Sheet Notes.
- 4) Modified/consolidated Keynote 16/17.
- 5) Removed conduit run to corridor from prep rooms on Tucker – Level 2.

ADD No 1, Tech. Item 4: **To the Drawings, Sheet T102, "FLOOR PLAN - CENTRAL HS - BUILDING B - SOUSA HALL,"**

- 1) Added halftone speaker clarification to Sheet Notes.
- 2) Added paint/finish clarification to Sheet Notes.
- 3) Clarified high-ceiling lift requirement item in Sheet Notes.
- 4) Modified/consolidated Keynote 16/17.
- 5) Changed verbiage of ADD ALTERNATE #3 note.

ADD No 1, Tech. Item 5: **To the Drawings, Sheet T103, "FLOOR PLAN - CENTRAL HS - BUILDING B - SOUSA HALL - REVISED WING,"**

- 1) Added halftone speaker clarification to Sheet Notes.
- 2) Added paint/finish clarification to Sheet Notes.
- 3) Clarified high-ceiling lift requirement item in Sheet Notes.
- 4) Modified/consolidated Keynote 16/17.

ADD No 1, Tech. Item 6: **To the Drawings, Sheet T104, "FLOOR PLAN - CENTRAL HS - BUILDING C - ROTC/POWELL,"**

- 1) Added halftone speaker clarification to Sheet Notes.
- 2) Added paint/finish clarification to Sheet Notes.
- 3) Clarified high-ceiling lift requirement item in Sheet Notes.
- 4) Modified/consolidated Keynote 16/17.

ADD No 1, Tech. Item 7: To the Drawings, Sheet T105, “FLOOR PLAN - CENTRAL HS - BUILDING D - KELTON AG,”

- 1) Added halftone speaker clarification to Sheet Notes.
- 2) Added paint/finish clarification to Sheet Notes.
- 3) Clarified high-ceiling lift requirement item in Sheet Notes.
- 4) Modified/consolidated Keynote 16/17.

ADD No 1, Tech. Item 8: To the Drawings, Sheet T106, “FLOOR PLAN - CENTRAL HS - BUILDING E - SMITH GYM,”

- 1) Added halftone speaker clarification to Sheet Notes.
- 2) Added paint/finish clarification to Sheet Notes.
- 3) Clarified high-ceiling lift requirement item in Sheet Notes.
- 4) Modified/consolidated Keynote 16/17.
- 5) Referenced high-ceiling sheet note in plans.

ADD No 1, Tech. Item 9: To the Drawings, Sheet T107, “FLOOR PLAN - CENTRAL HS - BUILDING F - DEDRICKSON AND TREVINO,”

- 1) Added halftone speaker clarification to Sheet Notes.
- 2) Added paint/finish clarification to Sheet Notes.
- 3) Clarified high-ceiling lift requirement item in Sheet Notes.
- 4) Modified/consolidated Keynote 16/17.
- 5) Added Keynote 07 to speaker/clock combos upstairs.

ADD No 1, Tech. Item 10: To the Drawings, Sheet T108, “FLOOR PLAN - CENTRAL HS - BUILDING G - MICHELANGELO,”

- 1) Added halftone speaker clarification to Sheet Notes.
- 2) Added paint/finish clarification to Sheet Notes.
- 3) Clarified high-ceiling lift requirement item in Sheet Notes.
- 4) Modified/consolidated Keynote 16/17.

ADD No 1, Tech. Item 11: To the Drawings, Sheet T109, “FLOOR PLAN - CENTRAL HS - BUILDING H - TENNIS,”

- 1) Added halftone speaker clarification to Sheet Notes.
- 2) Added paint/finish clarification to Sheet Notes.
- 3) Clarified high-ceiling lift requirement item in Sheet Notes.
- 4) Modified/consolidated Keynote 16/17.

ADD No 1, Tech. Item 12: To the Drawings, Sheet T110, “FLOOR PLAN - CENTRAL HS - BUILDING I - SCHWEITZER,”

- 1) Added halftone speaker clarification to Sheet Notes.
- 2) Added paint/finish clarification to Sheet Notes.
- 3) Clarified high-ceiling lift requirement item in Sheet Notes.
- 4) Modified/consolidated Keynote 16/17.

ADD No 1, Tech. Item 13: To the Drawings, Sheet T111, “FLOOR PLAN - CENTRAL HS - BUILDING J - HOLMES,”

- 1) Added halftone speaker clarification to Sheet Notes.
- 2) Added paint/finish clarification to Sheet Notes.
- 3) Clarified high-ceiling lift requirement item in Sheet Notes.
- 4) Modified/consolidated Keynote 16/17.

ADD No 1, Tech. Item 14: To the Drawings, Sheet T112, “FLOOR PLAN - CENTRAL HS - BUILDING K - BACON,”

- 1) Added halftone speaker clarification to Sheet Notes.
- 2) Added paint/finish clarification to Sheet Notes.
- 3) Clarified high-ceiling lift requirement item in Sheet Notes.
- 4) Modified/consolidated Keynote 16/17.

ADD No 1, Tech. Item 15: To the Drawings, Sheet T113, “FLOOR PLAN - CENTRAL HS - BUILDING M & L - CARLYLE & NEWTON,”

- 1) Added halftone speaker clarification to Sheet Notes.
- 2) Added paint/finish clarification to Sheet Notes.
- 3) Clarified high-ceiling lift requirement item in Sheet Notes.
- 4) Modified/consolidated Keynote 16/17.
- 5) Removed erroneous speaker from plan West of Newton Upstairs.

ADD No 1, Tech. Item 16: To the Drawings, Sheet T114, “FLOOR PLAN - CENTRAL HS - BUILDING N - TWAIN,”

- 1) Added halftone speaker clarification to Sheet Notes.
- 2) Added paint/finish clarification to Sheet Notes.
- 3) Clarified high-ceiling lift requirement item in Sheet Notes.
- 4) Modified/consolidated Keynote 16/17.

ADD No 1, Tech. Item 17: To the Drawings, Sheet T116, “FLOOR PLAN - LAKE VIEW HS - FIRST FLOOR - BUILDING A & B - AREA A,”

- 1) Added halftone speaker clarification to Sheet Notes.
- 2) Added paint/finish clarification to Sheet Notes.
- 3) Clarified high-ceiling lift requirement item in Sheet Notes.
- 4) Modified/consolidated Keynote 16/17.
- 5) Removed grey region and “Out of Scope” verbiage from plan region.

ADD No 1, Tech. Item 18: To the Drawings, Sheet T117, “FLOOR PLAN - LAKE VIEW HS - FIRST FLOOR - BUILDING A - AREA B,”

- 1) Added halftone speaker clarification to Sheet Notes.
- 2) Added paint/finish clarification to Sheet Notes.
- 3) Clarified high-ceiling lift requirement item in Sheet Notes.
- 4) Modified/consolidated Keynote 16/17.
- 5) Removed erroneously marked TC plan Southwest of Gym.
- 6) Removed single and double sided clock combos from corridor west of auditorium.
- 7) Removed note from room adjacent to auditorium noting future TC.
- 8) Revised/Reduced paging speaker layout in Admin area.

ADD No 1, Tech. Item 19: To the Drawings, Sheet T118, “FLOOR PLAN - LAKE VIEW HS - FIRST FLOOR - BUILDING A - AREA C,”

- 1) Added halftone speaker clarification to Sheet Notes.
- 2) Added paint/finish clarification to Sheet Notes.
- 3) Clarified high-ceiling lift requirement item in Sheet Notes.
- 4) Modified/consolidated Keynote 16/17.

ADD No 1, Tech. Item 20: To the Drawings, Sheet T119, "FLOOR PLAN - LAKE VIEW HS - SECOND FLOOR - BUILDING A - AREA C,"

- 1) Added halftone speaker clarification to Sheet Notes.
- 2) Added paint/finish clarification to Sheet Notes.
- 3) Clarified high-ceiling lift requirement item in Sheet Notes.
- 4) Modified/consolidated Keynote 16/17.

ADD No 1, Tech. Item 21: To the Drawings, Sheet T120, "FLOOR PLAN - LAKE VIEW HS - BUILDING C,"

- 1) Added halftone speaker clarification to Sheet Notes.
- 2) Added paint/finish clarification to Sheet Notes.
- 3) Clarified high-ceiling lift requirement item in Sheet Notes.
- 4) Modified/consolidated Keynote 16/17.

ADD No 1, Tech. Item 22: To the Drawings, Sheet T121, "FLOOR PLAN - LAKE VIEW HS - BUILDING D,"

- 1) Added halftone speaker clarification to Sheet Notes.
- 2) Added paint/finish clarification to Sheet Notes.
- 3) Clarified high-ceiling lift requirement item in Sheet Notes.
- 4) Modified/consolidated Keynote 16/17.

ADD No 1, Tech. Item 23: To the Drawings, Sheet T122, "FLOOR PLAN - LAKE VIEW HS - BUILDING G,"

- 1) Added halftone speaker clarification to Sheet Notes.
- 2) Added paint/finish clarification to Sheet Notes.
- 3) Clarified high-ceiling lift requirement item in Sheet Notes.
- 4) Modified/consolidated Keynote 16/17.

ADD No 1, Tech. Item 24: To the Drawings, Sheet T123, "FLOOR PLAN - LAKE VIEW HS - PORTABLES (SNACK SHACK),"

- 1) Added halftone speaker clarification to Sheet Notes.
- 2) Added paint/finish clarification to Sheet Notes.
- 3) Clarified high-ceiling lift requirement item in Sheet Notes.
- 4) Modified/consolidated Keynote 16/17.

ADD No 1, Tech. Item 25: To the Drawings, Sheet T124, "FLOOR PLAN - BELAIRE ES,"

- 1) Added halftone speaker clarification to Sheet Notes.
- 2) Added paint/finish clarification to Sheet Notes.
- 3) Clarified high-ceiling lift requirement item in Sheet Notes.
- 4) Modified/consolidated Keynote 16/17.
- 5) Removed address from view title.

ADD No 1, Tech. Item 26: To the Drawings, Sheet T125, "FLOOR PLAN - BONHAM ES,"

- 1) Added halftone speaker clarification to Sheet Notes.
- 2) Added paint/finish clarification to Sheet Notes.
- 3) Clarified high-ceiling lift requirement item in Sheet Notes.
- 4) Modified/consolidated Keynote 16/17.
- 5) Removed address from view title.

ADD No 1, Tech. Item 27: To the Drawings, Sheet T126, "FLOOR PLAN - BRADFORD ES,"

- 1) Added halftone speaker clarification to Sheet Notes.
- 2) Added paint/finish clarification to Sheet Notes.
- 3) Clarified high-ceiling lift requirement item in Sheet Notes.
- 4) Modified/consolidated Keynote 16/17.
- 5) Removed address from view title.

ADD No 1, Tech. Item 28: To the Drawings, Sheet T127, "FLOOR PLAN - FORT CONCHO ES,"

- 1) Reoriented Sheet Notes/Keynote Legend for legibility.
- 2) Added halftone speaker clarification to Sheet Notes.
- 3) Added paint/finish clarification to Sheet Notes.
- 4) Clarified high-ceiling lift requirement item in Sheet Notes.
- 5) Modified/consolidated Keynote 16/17.
- 6) Removed S1 paging speakers from room plan North of Library.
- 7) Added TC equipment to Library plan West wall and adjusted other devices to maintain plan legibility.
- 8) Added existing exterior S1 paging horn to plan South wall of Building C with Keynote 02.
- 9) Changed Keynote on existing exterior S1 paging horn on plan East wall of Building A to Keynote 01.

ADD No 1, Tech. Item 29: To the Drawings, Sheet T128, "FLOOR PLAN - GLENMORE ES,"

- 1) Added halftone speaker clarification to Sheet Notes.
- 2) Added paint/finish clarification to Sheet Notes.
- 3) Clarified high-ceiling lift requirement item in Sheet Notes.
- 4) Modified/consolidated Keynote 16/17.
- 5) Removed address from view title.
- 6) Removed halftone from TC-5 equipment in Building F Room 26 and also added Keynote 03 to that equipment.

ADD No 1, Tech. Item 30: To the Drawings, Sheet T129, "FLOOR PLAN - GOLIAD ES,"

- 1) Added halftone speaker clarification to Sheet Notes.
- 2) Added paint/finish clarification to Sheet Notes.
- 3) Clarified high-ceiling lift requirement item in Sheet Notes.
- 4) Modified/consolidated Keynote 16/17.
- 5) Removed address from view title.

ADD No 1, Tech. Item 31: To the Drawings, Sheet T130, "FLOOR PLAN - HOLIMAN ES,"

- 1) Added halftone speaker clarification to Sheet Notes.
- 2) Added paint/finish clarification to Sheet Notes.
- 3) Clarified high-ceiling lift requirement item in Sheet Notes.
- 4) Modified/consolidated Keynote 16/17.
- 5) Removed address from view title.

ADD No 1, Tech. Item 32: To the Drawings, Sheet T131, "FLOOR PLAN - LAMAR ES,"

- 1) Added halftone speaker clarification to Sheet Notes.
- 2) Added paint/finish clarification to Sheet Notes.
- 3) Clarified high-ceiling lift requirement item in Sheet Notes.
- 4) Modified/consolidated Keynote 16/17.
- 5) Removed address from view title.

ADD No 1, Tech. Item 33: To the Drawings, Sheet T132, "FLOOR PLAN - SANTA RITA ES,"

- 1) Added halftone speaker clarification to Sheet Notes.
- 2) Added paint/finish clarification to Sheet Notes.
- 3) Removed address from view title.

ADD No 1, Tech. Item 34: To the Drawings, Sheet T133, "FLOOR PLAN - LINCOLN ES,"

- 1) Added halftone speaker clarification to Sheet Notes.
- 2) Added paint/finish clarification to Sheet Notes.
- 3) Clarified high-ceiling lift requirement item in Sheet Notes.
- 4) Modified/consolidated Keynote 16/17.
- 5) Referenced high-ceiling sheet note in plans.
- 6) Removed address from view title.

ADD No 1, Tech. Item 35: To the Drawings, Sheet T134, "FLOOR PLAN - LONE STAR ES,"

- 1) Added halftone speaker clarification to Sheet Notes.
- 2) Added paint/finish clarification to Sheet Notes.
- 3) Clarified high-ceiling lift requirement item in Sheet Notes.
- 4) Modified/consolidated Keynote 16/17.
- 5) Removed address from view title.

ADD No 1, Tech. Item 36: To the Drawings, Sheet T135, "FLOOR PLAN - CENTRAL ON OAKS (DAEP/PAYS),"

- 1) Added halftone speaker clarification to Sheet Notes.
- 2) Added paint/finish clarification to Sheet Notes.
- 3) Clarified high-ceiling lift requirement item in Sheet Notes.
- 4) Modified/consolidated Keynote 16/17.
- 5) Removed address from view title.
- 6) Added existing AVR audio/video rack to Building F Level 1 Auditorium Stage.

ADD No 1, Tech. Item 37: To the Drawings, Sheet T136, "FLOOR PLAN - CENTRAL ON OAKS (DAEP/PAYS) GYM,"

- 1) Added halftone speaker clarification to Sheet Notes.
- 2) Added paint/finish clarification to Sheet Notes.
- 3) Clarified high-ceiling lift requirement item in Sheet Notes.
- 4) Modified/consolidated Keynote 16/17.
- 5) Added existing exterior S1 paging horn to plan West wall adjacent to Girls Gym with Keynote 02.

ADD No 1, Tech. Item 38: To the Drawings, Sheet T137, "FLOOR PLAN - AUSTIN PROFESSIONAL LEARNING (PL),"

- 1) Added halftone speaker clarification to Sheet Notes.
- 2) Added paint/finish clarification to Sheet Notes.
- 3) Clarified high-ceiling lift requirement item in Sheet Notes.
- 4) Modified/consolidated Keynote 16/17.
- 5) Added seal missing from title block.

ADD No 1, Tech. Item 39: To the Drawings, Sheet T138, "FLOOR PLAN - SAN JACINTO ES,"

- 1) Added halftone speaker clarification to Sheet Notes.
- 2) Added paint/finish clarification to Sheet Notes.
- 3) Clarified high-ceiling lift requirement item in Sheet Notes.
- 4) Modified/consolidated Keynote 16/17.



- 5) Removed address from view title and changed suffix to read "ADD ALTERNATE #2"
- 6) Changed Keynote on Cafeteria TR to Keynote 16.

ADD No 1, Tech. Item 40: **To the Drawings, Sheet T501, "TELECOM - DETAILS,"**

- 1) Added sheet in its entirety.

END OF ADDENDUM 01

SECTION 09 5113 – ACOUSTICAL PANEL CEILINGS

PART 1 - GENERAL

1.1 RELATED DOCUMENTS

- A. Drawings and general conditions of Contract, including General and Supplementary Conditions and Divisions-1 Specification sections apply to work of this section.

1.2 SUMMARY

- A. Scope
 - 1. Contractor shall provide and install a new ceiling tile after removal of existing loudspeakers. New ceiling tiles shall match surrounding tiles. When required, contractor shall provide clips to secure tiles in place in areas of return air systems.
- B. Section Includes
 - 1. Acoustical ceiling panels
- C. Related Sections
 - 1. Section 27 0000 "Communications Cabling"
 - 2. Section 27 5116 "Public Address Systems"

1.3 REFERENCES

- A. American Society for Testing and Materials (ASTM):
 - 1. ASTM A 1008 Standard Specification for Steel, Sheet, Cold Rolled, Carbon, Structural, High-Strength Low-Alloy and High-Strength Low-Alloy with Improved Formability
 - 2. ASTM A 641 Standard Specification for Zinc-Coated (Galvanized) Carbon Steel Wire
 - 3. ASTM A 653 Standard Specification for Steel Sheet, Zinc-Coated (Galvanized) by the Hot-Dip Process
 - 4. ASTM C 423 Sound Absorption and Sound Absorption Coefficients by the Reverberation Room Method
 - 5. ASTM C 635 Standard Specification for Metal Suspension Systems for Acoustical Tile and Lay-in Panel Ceilings
 - 6. ASTM C 636 Recommended Practice for Installation of Metal Ceiling Suspension Systems for Acoustical Tile and Lay-in Panels
 - 7. ASTM D 3273 Standard Test Method for Resistance to Growth of Mold on the Surface of Interior Coatings in an Environmental Chamber
 - 8. ASTM E 84 Standard Test Method for Surface Burning Characteristics of Building Materials
 - 9. ASTM E 580 Installation of Metal Suspension Systems in Areas Requiring Moderate Seismic Restraint
 - 10. ASTM E 1111 Standard Test Method for Measuring the Interzone Attenuation of Ceilings Systems
 - 11. ASTM E 1414 Standard Test Method for Airborne Sound Attenuation Between Rooms Sharing a Common Ceiling Plenum
 - 12. ASTM E 1264 Classification for Acoustical Ceiling Products
- B. International Building Code
- C. ASHRAE Standard 62.1-2004, Ventilation for Acceptable Indoor Air Quality
- D. NFPA 70 National Electrical Code

-
- E. ASCE 7 American Society of Civil Engineers, Minimum Design Loads for Buildings and Other Structures
 - F. International Code Council-Evaluation Services - AC 156 Acceptance Criteria for Seismic Qualification Testing of Non-structural Components
 - G. International Code Council-Evaluation Services Report - Seismic Engineer Report
 - 1. ESR 1308 - Armstrong Suspension Systems
 - H. International Association of Plumbing and Mechanical Officials - Seismic Engineer Report
 - 1. 0244 - Armstrong Single Span Suspension System
 - I. California Department of Public Health CDPH/EHLB/Standard Method v1.2 2017
 - J. LEED - Leadership in Energy and Environmental Design is a set of rating systems for the design, construction, operation, and maintenance of green buildings.
 - K. International Well Building Standard
 - L. Mindful Materials
 - M. Living Building Challenge
 - N. U.S. Department of Agriculture BioPreferred program (USDA BioPreferred).
 - O. Clean Rooms up to ISO Class 5 (Class 100)

1.4 SUBMITTALS

- A. Product Data: Submit manufacturer's technical data for each type of acoustical ceiling unit and suspension system required.
- B. Samples: Minimum 6-inch x 6-inch samples of specified acoustical panel; 8-inch-long samples of exposed wall molding and suspension system, including main runner and 4-foot cross tees.
- C. Shop Drawings: Layout and details of acoustical ceilings show locations of items that are to be coordinated with or supported by the ceilings.
- D. Acoustical Certifications: Manufacturer's certifications that products comply with specified requirements, including laboratory reports showing compliance with specified tests and standards. For acoustical performance, each carton of material must carry an approved independent laboratory classification, such as Underwriter's Laboratory (UL), of NRC, CAC, and AC.
 - 1. If the material supplied by the acoustical subcontractor does not have an independent laboratory classification of acoustical performance on every carton, subcontractor shall be required to send material from every production run appearing on the job to an independent or NVLAP approved laboratory for testing, at the architect's or owner's discretion. All products not conforming to manufacturer's current published values must be removed, disposed of, and replaced with complying product at the expense of the Contractor performing the work.

1.5 QUALITY ASSURANCE

- A. Single-Source Responsibility: Provide acoustical panel units and grid components by a single manufacturer to ensure fit and function.
- B. Installer Qualifications: Company specializing in performing specified work type, a minimum of three years of documented experience, and approved by the manufacturer.
- C. Fire Performance Characteristics: Identify acoustical ceiling components with appropriate markings of applicable testing and inspecting organization.
- D. Surface Burning Characteristics: Tested per ASTM E 84 and complying with ASTM E 1264 Classification.

1.6 DELIVERY, STORAGE AND HANDLING

-
- A. Deliver acoustical ceiling units to project site in original, unopened packages and store them in a fully enclosed space where they will be protected against damage from moisture, direct sunlight, surface contamination, and other causes.
 - B. Before installing acoustical ceiling units, permit them to reach room temperature and a stabilized moisture content.
 - C. Handle acoustical ceiling units carefully to avoid chipping edges or damaging units in any way.

1.7 WARRANTY

- A. Acoustical Panel: Submit a written warranty executed by the manufacturer, agreeing to repair or replace panels that fail within the warranty period. Failures include, but are not limited to the following:
 - 1. Acoustical Panels with HumiGuard® Max and HumiGuard® Plus performance: sagging and warping
 - 2. Acoustical panels with BioBlock® performance: growth of mold and mildew
 - 3. Grid System: rusting and manufacturer's defects.
- B. Warranty Period:
 - 1. Ceiling System: Thirty (30) years from date of substantial completion
 - 2. The Warranty shall not deprive the Owner of other rights the Owner may have under other provisions of the Contract Documents and will be in addition to and run concurrent with other warranties made by the Contractor under the requirements of the Contract Documents.

1.8 MAINTENANCE

- A. Extra Materials: Deliver extra materials to Owner. Furnish extra materials described below that match products installed. Packaged with protective covering for storage and identified with appropriate labels.
 - 1. Acoustical Ceiling Units: Furnish quality of full-size units equal to 5.0 percent of amount installed.
 - 2. Exposed Suspension System Components: Furnish quantity of each exposed suspension component equal to 2.0 percent of amount installed.

PART 2 - PRODUCTS

2.1 MANUFACTURERS

- A. Ceiling Panels:
 - 1. Armstrong World Industries, Inc.

2.2 ACOUSTICAL CEILING UNITS

- A. Acoustical Panel Ceilings
 - 1. Surface Texture: Medium Texture
 - 2. Composition: Mineral Fiber
 - 3. Color: White
 - 4. Size: 20 in x 60 in, 24 in x 24 in, 24 in x 48 in, 24 in x 60 in
 - 5. Edge Profile: Angled Tegal, Beveled Tegal, Square Lay-in
 - 6. Noise Reduction Coefficient (NRC) ASTM C 423 Classified w/ UL label on product carton: 0.55
 - 7. Ceiling Attenuation Class (CAC): ASTM E1414/E1414M; Classified with UL label on product carton: 33, 35, 40.

8. Flame Spread: ASTM E 1264; Class A
9. Light Reflectance (LR) White Panel: ASTM E 1477; 0.80
10. Dimensional Stability: Standard
11. Recycle Content: Up to 43% recycled total content. (Total recycled content: pre-consumer, post-consumer and post-industrial)
12. Material Ingredient Transparency: Health Product Declaration (HPD); Declare Label
13. Life Cycle Assessment: Third Party Certified Environmental Product Declaration (EPD)
14. Indoor Air Quality Certified to SCS-105 v4.2-2023.
15. Contractor is responsible for confirming compatibility with the existing grid suspension system at each building.
16. Acceptable Manufacturers:
 - a) Armstrong World Industries CORTEGA Model 769 (2' x 4')
 - b) Armstrong World Industries Model 933 (2' x 4')
 - c) Armstrong World Industries Model 2210 (2' x 2')
 - d) Armstrong World Industries Model 935A (2' x 2')**

2.3 METAL SUSPENSION SYSTEMS

- A. Contractor shall provide new ceiling tiles that are compatible with existing suspension system.

PART 3 - EXECUTION

3.1 EXAMINATION

- A. Do not proceed with installation until all wet work such as concrete, terrazzo, plastering and painting has been completed and thoroughly dried out, unless expressly permitted by manufacturer's printed recommendations. (Exception: HumiGuard Max Ceilings)

3.2 PREPARATION

- A. Measure each ceiling area and establish layout of acoustical units to balance border widths at opposite edges of each ceiling. Avoid use of less than half width units at borders and comply with reflected ceiling plans. Coordinate panel layout with mechanical and electrical fixtures.
- B. Coordination: Furnish layouts for preset inserts, clips, and other ceiling anchors whose installation is specified in other sections.
 1. Furnish concrete inserts and similar devices to other trades for installation well in advance of time needed for coordination of other work.

3.3 INSTALLATION

- A. Follow manufacturer installation instructions.
- B. Install suspension system and panels in accordance with the manufacturer's instructions, and in compliance with ASTM C 636 and with the authorities having jurisdiction.
- C. Suspend main beam from overhead construction with hanger wires spaced 4 feet on center along the length of the main runner. Install hanger wires plumb and straight.
- D. Install wall moldings at intersection of suspended ceiling and vertical surfaces. Miter corners where wall moldings intersect or install corner caps.

- E. For reveal edge panels: Cut and reveal or rabbet edges of ceiling panels at border areas and vertical surfaces.
- F. Install acoustical panels in coordination with suspended system, with edges resting on flanges of main runner and cross tees. Cut and fit panels neatly against abutting surfaces. Support edges by wall moldings.

3.4 ADJUSTING AND CLEANING

- A. Replace damaged and broken panels.
- B. Clean exposed surfaces of acoustical ceilings, including trim, edge moldings, and suspension members. Comply with manufacturer's instructions for cleaning and touch up of minor finish damage. Remove any ceiling products that cannot be successfully cleaned and or repaired. Replace with attic stock or new product to eliminate evidence of damage.

END OF SECTION

SAN ANGELO ISD PAGING UPGRADE

ALTERNATES:

ADD ALTERNATE 1: AUSTIN PROFESSIONAL LEARNING

ADD ALTERNATE 2: SAN JACINTO ES

SHEET INDEX	
Sheet Number	Sheet Name
TG100	COVER SHEET
TG101	GENERAL NOTES AND SYMBOLS
T102	FLOOR PLAN - CENTRAL HS - BUILDING A - TUCKER
T103	FLOOR PLAN - CENTRAL HS - BUILDING B - SOUSA HALL
T104	FLOOR PLAN - CENTRAL HS - BUILDING C - ROT/CROWELL
T105	FLOOR PLAN - CENTRAL HS - BUILDING D - KELTON AS
T106	FLOOR PLAN - CENTRAL HS - BUILDING E - SMITH GYM
T107	FLOOR PLAN - CENTRAL HS - BUILDING F - DEDRICKSON AND TREVINO
T108	FLOOR PLAN - CENTRAL HS - BUILDING G - MICHELANGELO
T109	FLOOR PLAN - CENTRAL HS - BUILDING H - TENNIS
T110	FLOOR PLAN - CENTRAL HS - BUILDING I - SCHWEITZER
T111	FLOOR PLAN - CENTRAL HS - BUILDING J - HOLMES
T112	FLOOR PLAN - CENTRAL HS - BUILDING K - BACON
T113	FLOOR PLAN - CENTRAL HS - BUILDING M & L - CARLYLE & NEWTON
T114	FLOOR PLAN - CENTRAL HS - BUILDING N - TWAIN
T115	OVERALL FLOOR PLAN - LAKE VIEW HS
T116	FLOOR PLAN - LAKE VIEW HS - FIRST FLOOR - BUILDING A & B - AREA A
T117	FLOOR PLAN - LAKE VIEW HS - FIRST FLOOR - BUILDING A - AREA B
T118	FLOOR PLAN - LAKE VIEW HS - FIRST FLOOR - BUILDING A - AREA C
T119	FLOOR PLAN - LAKE VIEW HS - SECOND FLOOR - BUILDING A - AREA C
T120	FLOOR PLAN - LAKE VIEW HS - BUILDING C
T121	FLOOR PLAN - LAKE VIEW HS - BUILDING D
T122	FLOOR PLAN - LAKE VIEW HS - BUILDING G
T123	FLOOR PLAN - LAKE VIEW HS - PORTABLES (SNACK SHACK)
T124	FLOOR PLAN - BELLAIRE FR
T125	FLOOR PLAN - BONHAM ES
T126	FLOOR PLAN - BRADFORD ES
T127	FLOOR PLAN - FORT CONCHO ES
T128	FLOOR PLAN - GLENMORE ES
T129	FLOOR PLAN - GOLDAES ES
T130	FLOOR PLAN - HOLMAN ES
T131	FLOOR PLAN - LAMAR ES
T132	FLOOR PLAN - SANTA RITA ES
T133	FLOOR PLAN - LINCOLN MS
T134	FLOOR PLAN - LOWE STAR MS
T135	FLOOR PLAN - CENTRAL ON OAKS (DAEPAYS)
T136	FLOOR PLAN - CENTRAL ON OAKS (DAEPAYS) GYM
T137	FLOOR PLAN - AUSTIN PROFESSIONAL LEARNING (PL)
T138	FLOOR PLAN - SAN JACINTO ES
T139	TELEPHONE - DETAILED

PROJECT ACRONYMS

GENERAL PROJECT NOTES

DATA SYMBOLS LEGEND



PUBLIC ADDRESS SYSTEM AND CLOCK SYMBOLS LEGEND

 Description |

SAN ANGELO ISD
PAGING UPGRADE
SAN ANGELO, TEXAS
D-SAN-1003-01

Project:



CRUX
TECHNOLOGY + SECURITY SOLUTIONS
800.685.6440
www.cruxsolutions.com


GENERAL NOTES AND SYMBOLS

Job. No. D-SAN-1003-01
Drawn By: CV
Designed By: CV
Date: 04/29/2026

Sheet No.
TG10

Autosave Docs:CRUX-San Angelo ISD Paging System Upgrade\B SAN-1003-01 SANSD HS Paging Upgrade, TECH, 02\HOSTED.rvt

2 FLOOR PLAN - CENTRAL HS - BUILDING A - TUCKER - LEVEL 2
T114 1/16" = 1'-0"

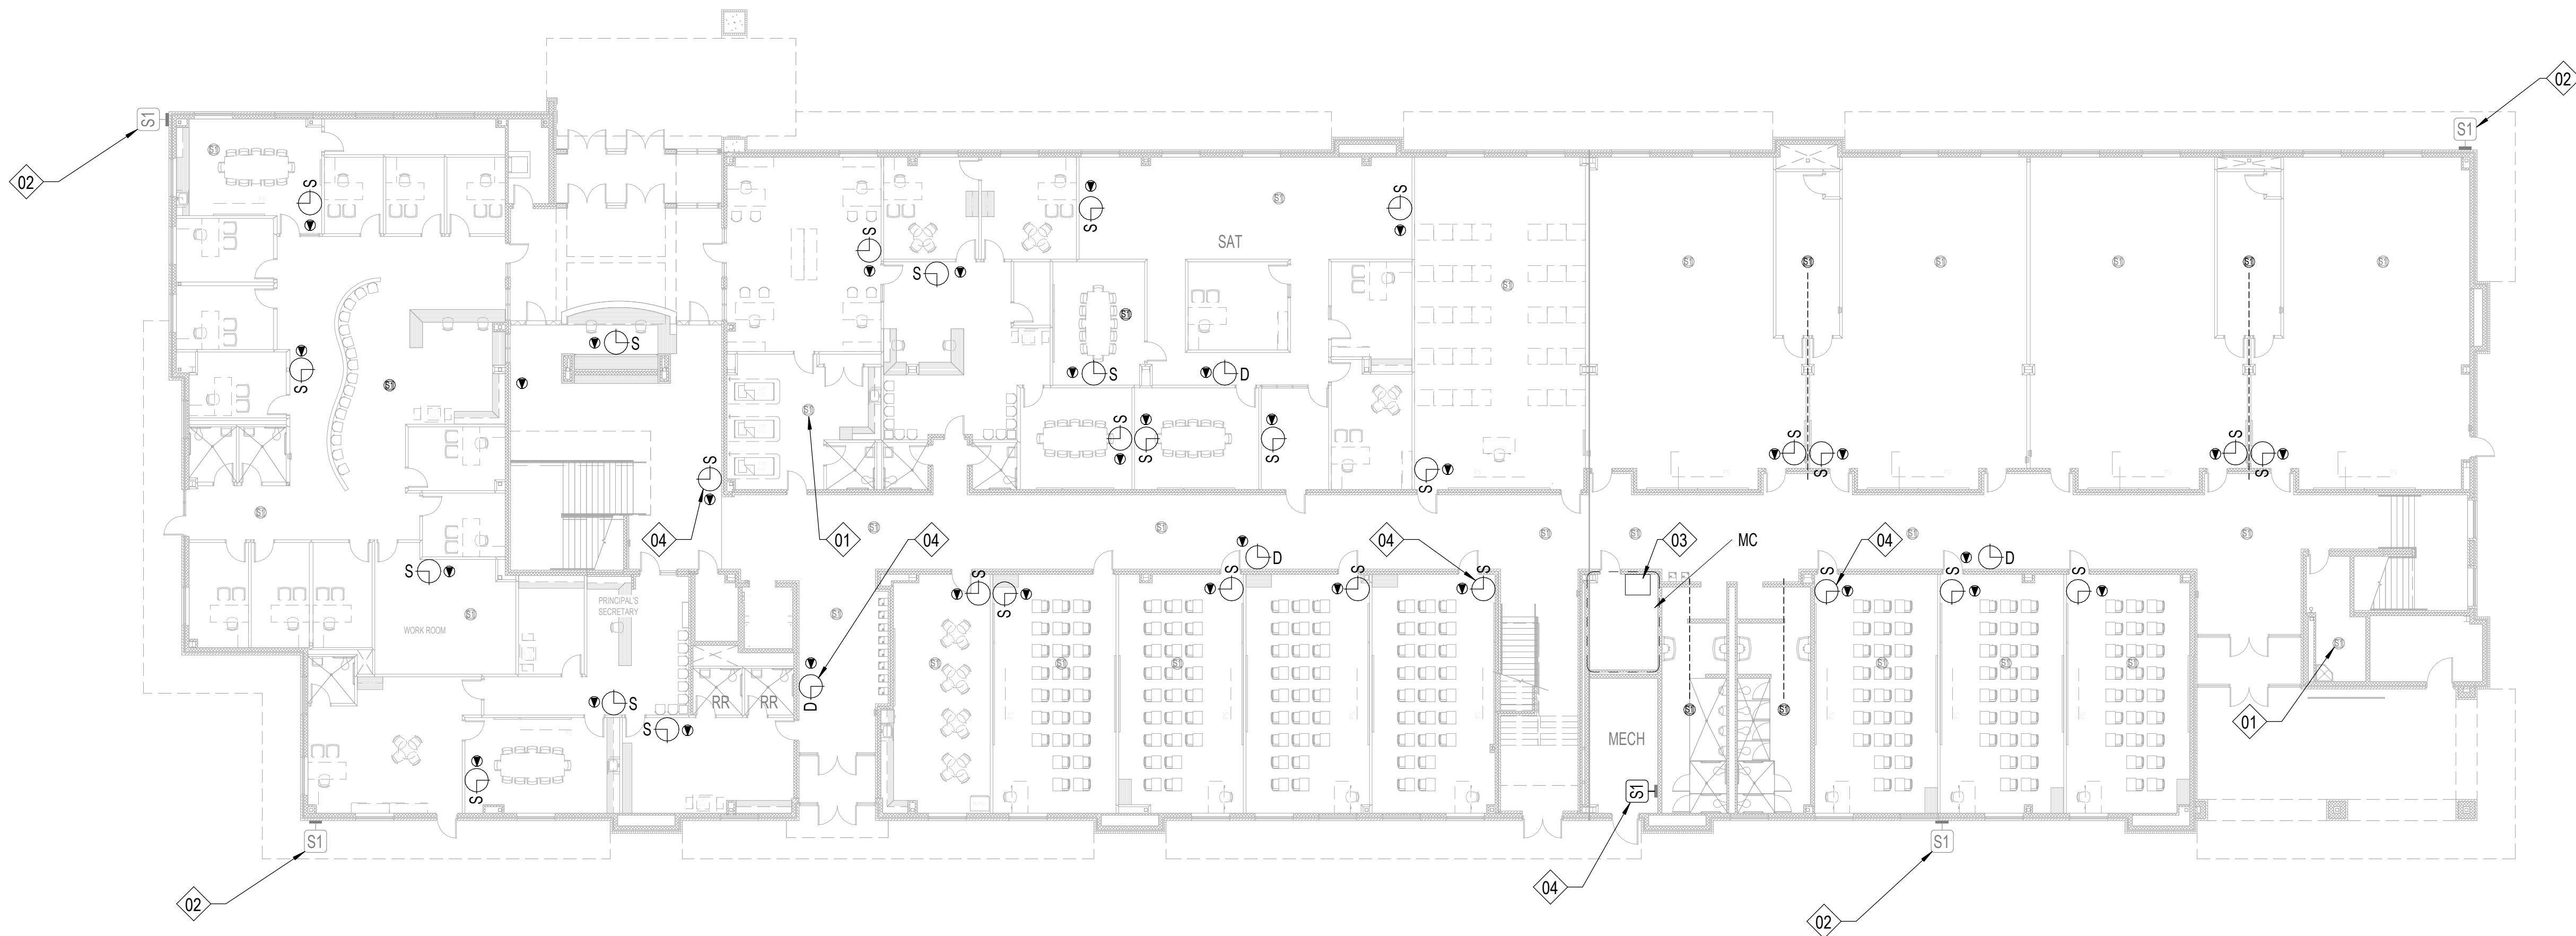

1 FLOOR PLAN - CENTRAL HS - BUILDING A - TUCKER - LEVEL 1
T101 1/16" = 1'-0"

SHEET NOTES:

REFERENCE SHEET TG101 FOR ALL SYMBOLS AND PROJECT SPECIFIC NOTES.

EXISTING PAGING SPEAKERS (S1) ARE SHOWN IN HALF-TONE. CONTRACTOR SHALL REMOVE EXISTING PAGING SPEAKERS (S1) AND REPLACE WITH CEILING TILE OR BLANK COVER PLATE, UNO.

ALL CONDUITS SHALL BE 1" FOR ALL DEVICES UNLESS NOTED OTHERWISE ON THE TECHNOLOGY DRAWINGS.

IN AREAS WITH CONCRETE OR MASONRY WALLS, CONTRACTOR SHALL PROVIDE SURFACE RACEWAY SYSTEM.

IN AREAS WITH EXPOSED CEILINGS, CONTRACTOR SHALL INSTALL ALL CABLING IN CONDUIT. CONTRACTOR SHALL PERFORM PAINT FINISH AS COORDINATED WITH OWNER.

CONTRACTOR SHALL DEMOLISH ANY UNUSED CABLING BACK TO ITS ORIGIN AND DISPOSE.

CONTRACTOR SHALL REPLACE ALL EXISTING PTT BUTTONS PRESENT IN THE FACILITY WITH A BLANK COVER PLATE. CONTRACTOR SHALL LOCATE, DOCUMENT AND REMEDIATE IN THE SAME METHOD ANY PTT BUTTON NOT EXPLICITLY SHOWN IN THIS DRAWING SET.

CONTRACTOR IS RESPONSIBLE FOR PROVIDING LIFT FOR ALL HIGH CEILING AREAS (FINE ARTS, GYM, ETC.). CONTRACTOR SHALL ALSO BE REQUIRED TO PROVIDE FLOORING PROTECTION.

KEYNOTE LEGEND

(NOT ALL KEYNOTES MAY APPLY)

01. EXISTING, CONTRACTOR SHALL REPLACE WITH NEW DEVICE AND NEW CABLING. CEILING TILE MAY REMAIN IN PLACE UNLESS DAMAGED.

02. EXISTING, TO REMAIN. CONTRACTOR SHALL INSTALL BRIDGE FROM ANALOG SPEAKER TO IP HEAD END.

03. CONTRACTOR SHALL COMPLETELY REMOVE ALL ABANDONED ANALOG SPEAKER WIRING AND SUPPORTING TERMINAL BLOCKS FROM THE FACILITY. TERMINAL BLOCKS THAT SUPPORT OTHER EXISTING DEVICES SHALL REMAIN.

04. INSTALL PLASTIC 1/2" RACEWAY FOR PATCH CABLE TO TOP OF SURFACE MOUNTED CLOCK BACK BOX. TERMINATE DATA ABOVE CEILING.

05. EXISTING, CONTRACTOR SHALL REMOVE DEVICE, DEMOLISH CABLING BACK TO ITS ORIGIN, AND INSTALL NEW BLANK FACEPLATE.

06. INSTALL DATA IN ADJACENT OVERHEAD CEILING SPACE. PROVIDE 1" SLEEVE THROUGH CMU WALL TO BACK OF CLOCK DISPLAY.

07. SURFACE MOUNTED CONDUIT NEEDED FOR ALL NEW PAGING AND RELATED DEVICES.

08. PROVIDE 1" CONDUIT TO TOP OF SURFACE MOUNTED CLOCK BACK BOX FOR PATCH CABLE. DATA SHALL BE TERMINATED ABOVE CEILING.

09. INSTALL SURFACE MOUNTED RACEWAY FROM DEVICE BACK TO TECH CLOSET LOCATION.

10. CEILING SPEAKER IN CAN MOUNTED TO STRUCTURAL STEEL.

11. THIS IS A PLASTER CEILING, CONDUIT OR PLASTIC RACEWAY WILL NEED TO BE SECURED TO THE CEILING ITSELF.

12. SPEAKERS MOUNTED TO STRUCTURAL STEEL.

13. INSTALL SURFACE RACEWAY FOR ENTIRE PATH FROM TC TO DEVICE.

14. EXISTING SPEAKER BUILT FLUSH IN WALL. DO NOT REMOVE. INSTALL NEW DEVICE ADJACENT TO EXISTING. INSTALL DATA DROP IN ACCESSIBLE CEILING IN ADJACENT SPACE.

15. REMOVE EXISTING HORNS AND LEAVE MOUNTS INTACT, REMOVE EXISTING CABLING. INSTALL NEW DUAL SIDED DEVICE ADJACENT TO FORMER HORN LOCATION. INSTALL DATA IN ADJACENT CEILING SPACE.

16. REFERENCE DIV 27 FOR RACK INFORMATION AND ALLOWANCE REQUIREMENTS. FINAL LOCATIONS TO BE COORDINATED WITH OWNER PRIOR TO INSTALLATION.

17. NOT USED.

18. RECENTLY INSTALLED SPEAKER, REMOVE, PROTECT, AND REDEPLOY WHERE OTHER NEW ANALOG CEILING SPEAKERS ARE NEEDED.

19. J-BOX LARGER THAN 4X4" NEEDED HERE. PROVIDE ADDITIONAL SLACK FOR FUTURE RETERMINATIONS.

20. FIELD CONDITIONS MAY DIFFER FROM WHAT IS SHOWN. COORDINATE EXACT LOCATION WITH OWNER.

21. GYP CEILING. CONTRACTOR SHALL ACCOUNT FOR THREE (3) 24"X24" ACCESS PANEL LOCATIONS IN PRICING. VERIFY PATHWAYS ON SITE.

Description

Addendum 01

Date: 05/18/25

Revision: 1

SAN ANGELO ISD
PAGING UPGRADE
SAN ANGELO, TEXAS
D-SAN-1003-01

Project:



CRUX
TECHNOLOGY • SECURITY SOLUTIONS
800.665.6440
www.cruxsolutions.com

FLOOR PLAN - CENTRAL
HS - BUILDING A - TUCKER

Job No.

D-SAN-1003-01

Drawn By:

CV

Designed By:

CV

Date:

04/29/2025

Sheet No.

T101

Autodesk Docs\CRUX-San Angelo ISD Paging System Upgrade\B-SAN-1003-01 SANSD ISD Paging Upgrade, TECH, 02\HOSTED\rv4



1 FLOOR PLAN - CENTRAL HS - BUILDING B - SOUSA HALL - SECOND FLOOR
T102 3/32" = 1'-0"

SHEET NOTES:

REFERENCE SHEET TG101 FOR ALL SYMBOLS AND PROJECT SPECIFIC NOTES.

EXISTING PAGING SPEAKERS (S1) ARE SHOWN IN HALF-TONE. CONTRACTOR SHALL REMOVE EXISTING PAGING SPEAKERS (S1) AND REPLACE WITH CEILING TILE OR BLANK COVER PLATE, U.N.O.

ALL CONDUITS SHALL BE 1" FOR ALL DEVICES UNLESS NOTED OTHERWISE ON THE TECHNOLOGY DRAWINGS.

IN AREAS WITH CONCRETE OR MASONRY WALLS, CONTRACTOR SHALL PROVIDE SURFACE RACEWAY SYSTEM.

IN AREAS WITH EXPOSED CEILINGS, CONTRACTOR SHALL INSTALL ALL CABLING IN CONDUIT. CONTRACTOR TO PERFORM PAINT FINISH AS COORDINATED WITH OWNER.

CONTRACTOR SHALL DEMOLISH ANY UNUSED CABLING BACK TO ITS ORIGIN AND DISPOSE.

CONTRACTOR SHALL REPLACE ALL EXISTING PTT BUTTONS PRESENT IN THE FACILITY WITH A BLANK COVER PLATE. CONTRACTOR SHALL LOCATE, DOCUMENT AND REMEDIATE IN THE SAME METHOD ANY PTT BUTTON NOT EXPLICITLY SHOWN IN THIS DRAWING SET.

CONTRACTOR IS RESPONSIBLE FOR PROVIDING LIFT FOR ALL HIGH CEILING AREAS (FINE ARTS, GYMS, ETC.). CONTRACTOR SHALL ALSO BE REQUIRED TO PROVIDE FLOORING PROTECTION.

KEYNOTE LEGEND

(NOT ALL KEYNOTES MAY APPLY.)

01. EXISTING, CONTRACTOR SHALL REPLACE WITH NEW DEVICE AND NEW CABLING. CEILING TILE MAY REMAIN IN PLACE UNLESS DAMAGED.

02. EXISTING, TO REMAIN. CONTRACTOR SHALL INSTALL BRIDGE FROM ANALOG SPEAKER TO IP HEAD END.

03. CONTRACTOR SHALL COMPLETELY REMOVE ALL ABANDONED ANALOG SPEAKER WIRING AND SUPPORTING TERMINAL BLOCKS FROM THE FACILITY. TERMINAL BLOCKS THAT SUPPORT OTHER EXISTING DEVICES SHALL REMAIN.

04. INSTALL PLASTIC 1/2" RACEWAY FOR PATCH CABLE TO TOP OF SURFACE MOUNTED CLOCK BACK BOX. TERMINATE DATA ABOVE CEILING.

05. EXISTING, CONTRACTOR SHALL REMOVE DEVICE. DEMOLISH CABLING BACK TO ITS ORIGIN, AND INSTALL NEW BLANK FACEPLATE.

06. INSTALL DATA IN ADJACENT OVERHEAD CEILING SPACE. PROVIDE 1" SLEEVE THROUGH CMU WALL TO BACK OF CLOCK DISPLAY.

07. SURFACE MOUNTED CONDUIT NEEDED FOR ALL NEW PAGING AND RELATED DEVICES.

08. PROVIDE 1" CONDUIT TO TOP OF SURFACE MOUNTED CLOCK BACK BOX FOR PATCH CABLE. DATA SHALL BE TERMINATED ABOVE CEILING.

09. INSTALL SURFACE MOUNTED RACEWAY FROM DEVICE BACK TO TECH CLOSET LOCATION.

10. CEILING SPEAKER IN CAN MOUNTED TO STRUCTURAL STEEL.

11. THIS IS A PLASTER CEILING. CONDUIT OR PLASTIC RACEWAY WILL NEED TO BE SECURED TO THE CEILING ITSELF.

12. SPEAKERS MOUNTED TO STRUCTURAL STEEL.

13. INSTALL SURFACE RACEWAY FOR ENTIRE PATH FROM TC TO DEVICE.

14. EXISTING SPEAKER BUILT FLUSH IN WALL. DO NOT REMOVE. INSTALL NEW DEVICE ADJACENT TO EXISTING. INSTALL DATA DROP IN ACCESSIBLE CEILING IN ADJACENT SPACE.

15. REMOVE EXISTING HORNS AND LEAVE MOUNTS INTACT. REMOVE EXISTING CABLING. INSTALL NEW DUAL-SIDED DEVICE ADJACENT TO FORMER HORN LOCATION. INSTALL DATA IN ADJACENT CEILING SPACE.

16. REFERENCE DIV 27 FOR RACK INFORMATION AND ALLOWANCE REQUIREMENTS. FINAL LOCATIONS TO BE COORDINATED WITH OWNER PRIOR TO INSTALLATION.


17. NOT USED.

18. RECENTLY INSTALLED SPEAKER. REMOVE, PROTECT, AND REDEPLOY WHERE OTHER NEW ANALOG CEILING SPEAKERS ARE NEEDED.

19. J-BOX LARGER THAN 4X4" NEEDED HERE. PROVIDE ADDITIONAL SLACK FOR FUTURE RETERMINATIONS.

20. FIELD CONDITIONS MAY DIFFER FROM WHAT IS SHOWN. COORDINATE EXACT LOCATION WITH OWNER.

21. GYP CEILING. CONTRACTOR SHALL ACCOUNT FOR THREE (3) 24"X24" ACCESS PANEL LOCATIONS IN PRICING. VERIFY PATHWAYS ON SITE.

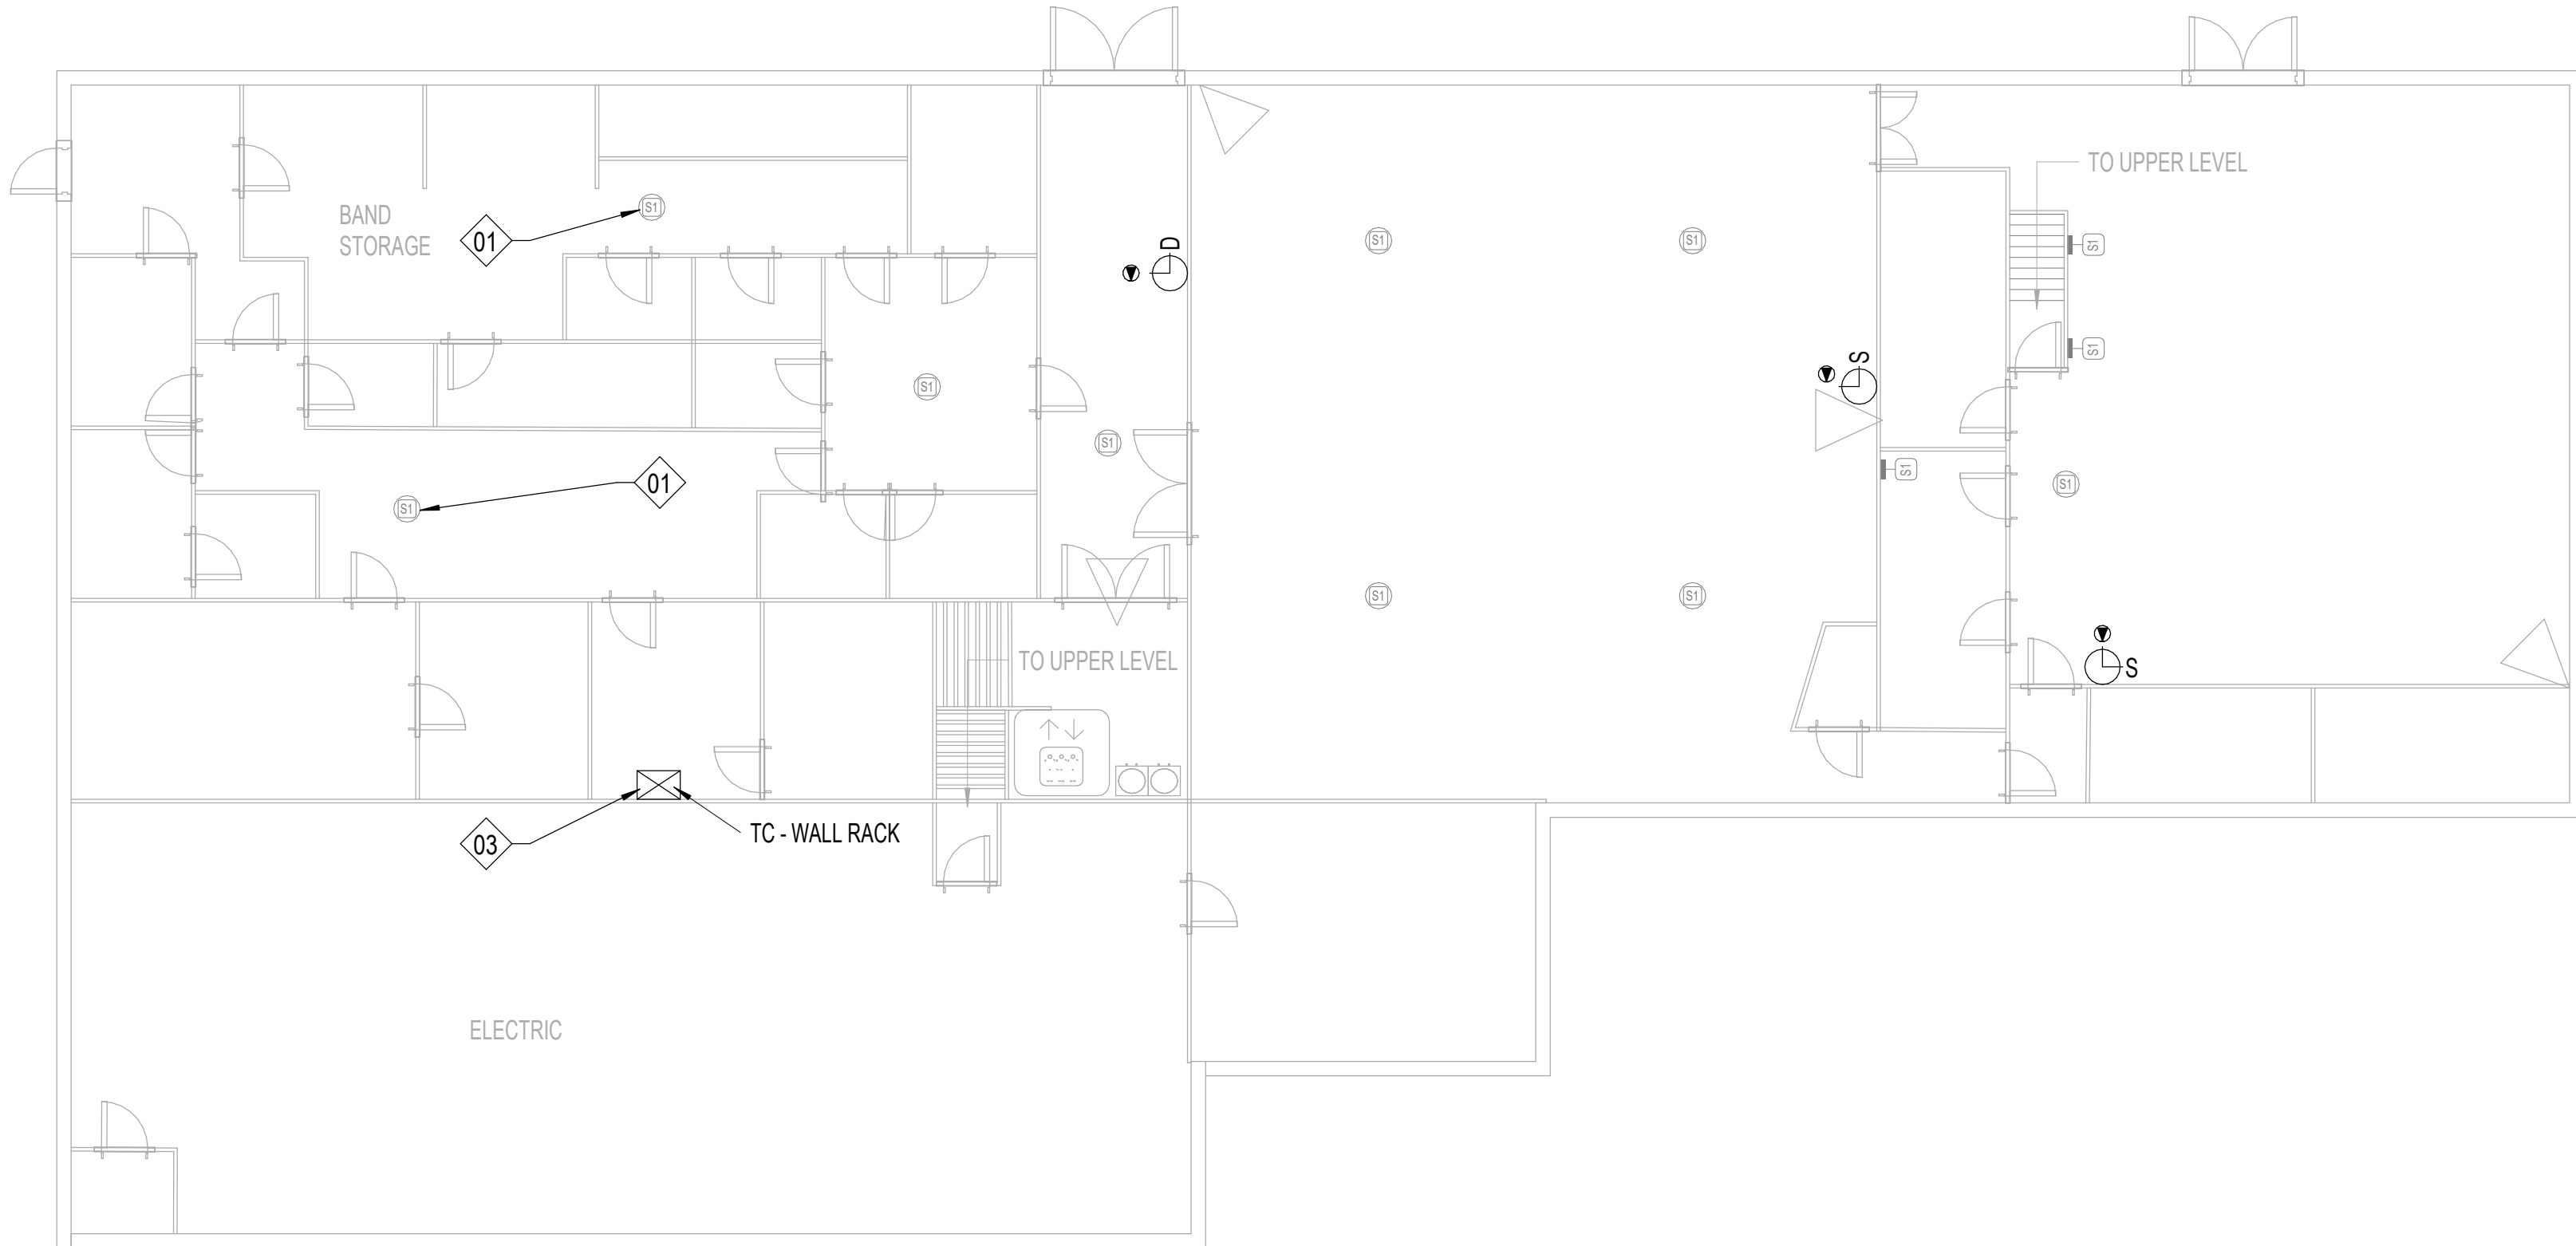

2 FLOOR PLAN - CENTRAL HS - BUILDING B - SOUSA HALL - FIRST FLOOR
T102 3/32" = 1'-0"

Description

Addendum 01

Date: 05/18/25

Revision: 1

SAN ANGELO ISD
PAGING UPGRADE
SAN ANGELO, TEXAS
D-SAN-1003-01

Project:



FLOOR PLAN - CENTRAL
HS - BUILDING B - SOUSA
HALL

Job No.
D-SAN-1003-01
Drawn By:
CV
Designed By:
CV
Date:
04/29/2025

Sheet No.
T102

Autosave Docs:CRUX-San Angelo ISD Paging System Upgrade\B-SAN-1003-01 SANSD-103_Paging Upgrade_Tech_02(HOSTED).rvt



SHEET NOTES:

REFERENCE SHEET TG101 FOR ALL SYMBOLS AND PROJECT SPECIFIC NOTES.

EXISTING PAGING SPEAKERS (S1) ARE SHOWN IN HALF-TONE. CONTRACTOR SHALL REMOVE EXISTING PAGING SPEAKERS (S1) AND REPLACE WITH CEILING TILE OR BLANK COVER PLATE, UNO.

ALL CONDUITS SHALL BE 1" FOR ALL DEVICES UNLESS NOTED OTHERWISE ON THE TECHNOLOGY DRAWINGS.

IN AREAS WITH CONCRETE OR MASONRY WALLS, CONTRACTOR SHALL PROVIDE SURFACE RACEWAY SYSTEM.

IN AREAS WITH EXPOSED CEILINGS, CONTRACTOR SHALL INSTALL ALL CABLING IN CONDUIT. CONTRACTOR TO PERFORM PAINT FINISH AS COORDINATED WITH OWNER.

CONTRACTOR SHALL DEMOLISH ANY UNUSED CABLING BACK TO ITS ORIGIN AND DISPOSE.

CONTRACTOR SHALL REPLACE ALL EXISTING PTT BUTTONS PRESENT IN THE FACILITY WITH A BLANK COVER PLATE. CONTRACTOR SHALL LOCATE, DOCUMENT AND REMEDIATE IN THE SAME METHOD ANY PTT BUTTON NOT EXPLICITLY SHOWN IN THIS DRAWING SET.

CONTRACTOR IS RESPONSIBLE FOR PROVIDING LIFT FOR ALL HIGH CEILING AREAS (FINE ARTS, GYM, ETC.). CONTRACTOR SHALL ALSO BE REQUIRED TO PROVIDE FLOORING PROTECTION.

KEYNOTE LEGEND

(NOT ALL KEYNOTES MAY APPLY)

01. EXISTING, CONTRACTOR SHALL REPLACE WITH NEW DEVICE AND NEW CABLING. CEILING TILE MAY REMAIN IN PLACE UNLESS DAMAGED.

02. EXISTING, TO REMAIN. CONTRACTOR SHALL INSTALL BRIDGE FROM ANALOG SPEAKER TO IP HEAD END.

03. CONTRACTOR SHALL COMPLETELY REMOVE ALL ABANDONED ANALOG SPEAKER WIRING AND SUPPORTING TERMINAL BLOCKS FROM THE FACILITY. TERMINAL BLOCKS THAT SUPPORT OTHER EXISTING DEVICES SHALL REMAIN.

04. INSTALL PLASTIC 1/2" RACEWAY FOR PATCH CABLE TO TOP OF SURFACE MOUNTED CLOCK BACK BOX. TERMINATE DATA ABOVE CEILING.

05. EXISTING, CONTRACTOR SHALL REMOVE DEVICE, DEMOLISH CABLING BACK TO ITS ORIGIN, AND INSTALL NEW BLANK FACEPLATE.

06. INSTALL DATA IN ADJACENT OVERHEAD CEILING SPACE. PROVIDE 1" SLEEVE THROUGH CMU WALL TO BACK OF CLOCK DISPLAY.

07. SURFACE MOUNTED CONDUIT NEEDED FOR ALL NEW PAGING AND RELATED DEVICES.

08. PROVIDE 1" CONDUIT TO TOP OF SURFACE MOUNTED CLOCK BACK BOX FOR PATCH CABLE. DATA SHALL BE TERMINATED ABOVE CEILING.

09. INSTALL SURFACE MOUNTED RACEWAY FROM DEVICE BACK TO TECH CLOSET LOCATION.

10. CEILING SPEAKER IN CAN MOUNTED TO STRUCTURAL STEEL.

11. THIS IS A PLASTER CEILING, CONDUIT OR PLASTIC RACEWAY WILL NEED TO BE SECURED TO THE CEILING ITSELF.

12. SPEAKERS MOUNTED TO STRUCTURAL STEEL.

13. INSTALL SURFACE RACEWAY FOR ENTIRE PATH FROM TC TO DEVICE.

14. EXISTING SPEAKER BUILT FLUSH IN WALL. DO NOT REMOVE. INSTALL NEW DEVICE ADJACENT TO EXISTING. INSTALL DATA DROP IN ACCESSIBLE CEILING IN ADJACENT SPACE.

15. REMOVE EXISTING HORNS AND LEAVE MOUNTS INTACT, REMOVE EXISTING CABLING. INSTALL NEW DUAL SIDED DEVICE ADJACENT TO FORMER HORN LOCATION. INSTALL DATA IN ADJACENT CEILING SPACE.

16. REFERENCE DIV 27 FOR RACK INFORMATION AND ALLOWANCE REQUIREMENTS. FINAL LOCATIONS TO BE COORDINATED WITH OWNER PRIOR TO INSTALLATION.

17. NOT USED.

18. RECENTLY INSTALLED SPEAKER, REMOVE, PROTECT, AND REDEPLOY WHERE OTHER NEW ANALOG CEILING SPEAKERS ARE NEEDED.

19. J-BOX LARGER THAN 4X4" NEEDED HERE. PROVIDE ADDITIONAL SLACK FOR FUTURE RETERMINATIONS.

20. FIELD CONDITIONS MAY DIFFER FROM WHAT IS SHOWN. COORDINATE EXACT LOCATION WITH OWNER.

21. GYP CEILING. CONTRACTOR SHALL ACCOUNT FOR THREE (3) 24"X24" ACCESS PANEL LOCATIONS IN PRICING. VERIFY PATHWAYS ON SITE.

Description

Addendum 01

Date: 05/18/25

Revision: 1

Project:

SAN ANGELO ISD
PAGING UPGRADE
SAN ANGELO, TEXAS
D-SAN-1003-01



CRUX
TECHNOLOGY • SECURITY SOLUTIONS
800.665.6440
www.cruxsolutions.com

FLOOR PLAN - CENTRAL
HS - BUILDING B - SOUSA
HALL - REVISED WING

Job No.

D-SAN-1003-01

Drawn By:

CV

Designed By:

CV


Date:

04/29/2025

Sheet No.

T103

1 FLOOR PLAN - CENTRAL HS - BUILDING C - ROTC/POWELL
T104 1/8" = 1'-0"

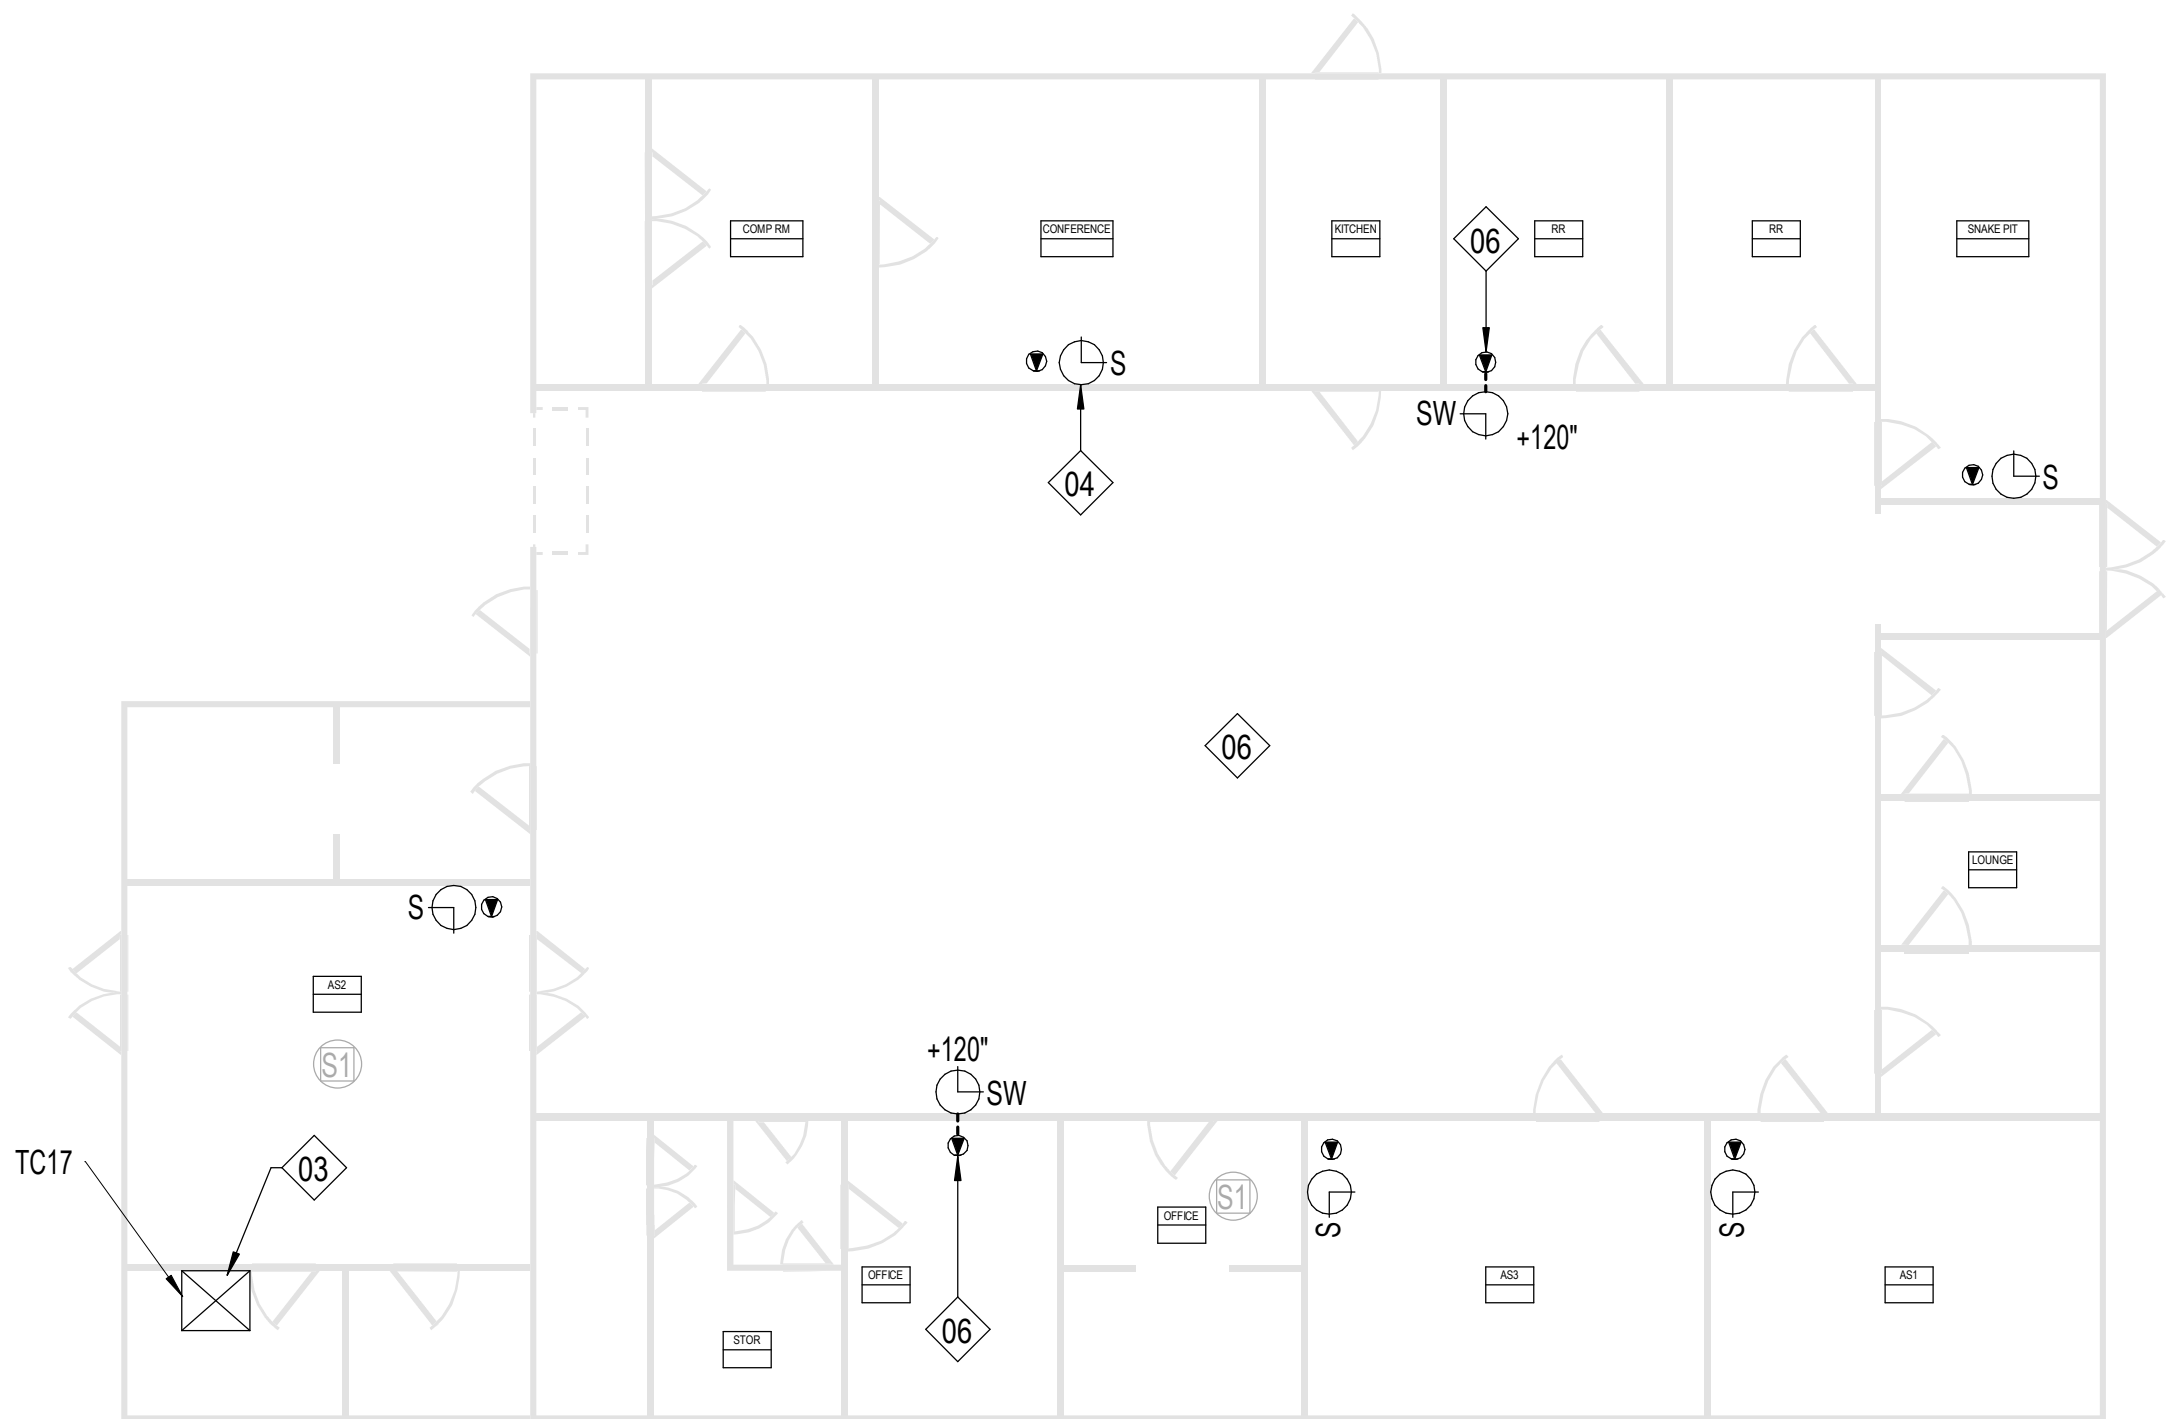

SHEET NOTES:

REFERENCE SHEET TG101 FOR ALL SYMBOLS AND PROJECT SPECIFIC NOTES.

EXISTING PAGING SPEAKERS (S1) ARE SHOWN IN HALF-TONE. CONTRACTOR SHALL REMOVE EXISTING PAGING SPEAKERS (S1) AND REPLACE WITH CEILING TILE OR BLANK COVER PLATE, UNLESS NOTED OTHERWISE.

ALL CONDUITS SHALL BE 1" FOR ALL DEVICES UNLESS NOTED OTHERWISE ON THE TECHNOLOGY DRAWINGS.

IN AREAS WITH CONCRETE OR MASONRY WALLS, CONTRACTOR SHALL PROVIDE SURFACE RACEWAY SYSTEM.

IN AREAS WITH EXPOSED CEILINGS, CONTRACTOR SHALL INSTALL ALL CABLING IN CONDUIT. CONTRACTOR TO PERFORM PAINT FINISH AS COORDINATED WITH OWNER.

CONTRACTOR SHALL DEMOLISH ANY UNUSED CABLING BACK TO ITS ORIGIN AND DISPOSE.

CONTRACTOR SHALL REPLACE ALL EXISTING PTT BUTTONS PRESENT IN THE FACILITY WITH A BLANK COVER PLATE. CONTRACTOR SHALL LOCATE, DOCUMENT AND REMEDIATE IN THE SAME METHOD ANY PTT BUTTON NOT EXPLICITLY SHOWN IN THIS DRAWING SET.

CONTRACTOR IS RESPONSIBLE FOR PROVIDING LIFT FOR ALL HIGH CEILING AREAS (FINE ARTS, GYM, ETC.). CONTRACTOR SHALL ALSO BE REQUIRED TO PROVIDE FLOORING PROTECTION.

KEYNOTE LEGEND

(NOT ALL KEYNOTES MAY APPLY.)

01. EXISTING, CONTRACTOR SHALL REPLACE WITH NEW DEVICE AND NEW CABLING. CEILING TILE MAY REMAIN IN PLACE UNLESS DAMAGED.
02. EXISTING, TO REMAIN. CONTRACTOR SHALL INSTALL BRIDGE FROM ANALOG SPEAKER TO IP HEAD END.
03. CONTRACTOR SHALL COMPLETELY REMOVE ALL ABANDONED ANALOG SPEAKER WIRING AND SUPPORTING TERMINAL BLOCKS FROM THE FACILITY. TERMINAL BLOCKS THAT SUPPORT OTHER EXISTING DEVICES SHALL REMAIN.
04. INSTALL PLASTIC 1/2" RACEWAY FOR PATCH CABLE TO TOP OF SURFACE MOUNTED CLOCK BACK BOX. TERMINATE DATA ABOVE CEILING.
05. EXISTING, CONTRACTOR SHALL REMOVE DEVICE, DEMOLISH CABLING BACK TO ITS ORIGIN, AND INSTALL NEW BLANK FACEPLATE.
06. INSTALL DATA IN ADJACENT OVERHEAD CEILING SPACE. PROVIDE 1" SLEEVE THROUGH CMU WALL TO BACK OF CLOCK DISPLAY.
07. SURFACE MOUNTED CONDUIT NEEDED FOR ALL NEW PAGING AND RELATED DEVICES.
08. PROVIDE 1" CONDUIT TO TOP OF SURFACE MOUNTED CLOCK BACK BOX FOR PATCH CABLE. DATA SHALL BE TERMINATED ABOVE CEILING.
09. INSTALL SURFACE MOUNTED RACEWAY FROM DEVICE BACK TO TECH CLOSET LOCATION.
10. CEILING SPEAKER IN CAN MOUNTED TO STRUCTURAL STEEL.
11. THIS IS A PLASTER CEILING, CONDUIT OR PLASTIC RACEWAY WILL NEED TO BE SECURED TO THE CEILING ITSELF.
12. SPEAKERS MOUNTED TO STRUCTURAL STEEL.
13. INSTALL SURFACE RACEWAY FOR ENTIRE PATH FROM TC TO DEVICE.
14. EXISTING SPEAKER BUILT FLUSH IN WALL. DO NOT REMOVE. INSTALL NEW DEVICE ADJACENT TO EXISTING. INSTALL DATA DROP IN ACCESSIBLE CEILING IN ADJACENT SPACE.
15. REMOVE EXISTING HORNS AND LEAVE MOUNTS INTACT, REMOVE EXISTING CABLING. INSTALL NEW DUAL SIDED DEVICE ADJACENT TO FORMER HORN LOCATION. INSTALL DATA IN ADJACENT CEILING SPACE.
16. REFERENCE DIV 27 FOR RACK INFORMATION AND ALLOWANCE REQUIREMENTS. FINAL LOCATIONS TO BE COORDINATED WITH OWNER PRIOR TO INSTALLATION.
17. NOT USED.
18. RECENTLY INSTALLED SPEAKER, REMOVE, PROTECT, AND REDEPLOY WHERE OTHER NEW ANALOG CEILING SPEAKERS ARE NEEDED.
19. J-BOX LARGER THAN 4X4" NEEDED HERE. PROVIDE ADDITIONAL SLACK FOR FUTURE RETERMINATIONS.
20. FIELD CONDITIONS MAY DIFFER FROM WHAT IS SHOWN. COORDINATE EXACT LOCATION WITH OWNER.
21. GYP CEILING. CONTRACTOR SHALL ACCOUNT FOR THREE (3) 24"X24" ACCESS PANEL LOCATIONS IN PRICING. VERIFY PATHWAYS ON SITE.

Description

Date :

Revision:

Project:

SAN ANGELO ISD
PAGING UPGRADE
SAN ANGELO, TEXAS
D-SAN-1003-01



CRUX
TECHNOLOGY • SECURITY SOLUTIONS
800.665.6440
www.cruxsolutions.com

FLOOR PLAN - CENTRAL
HS - BUILDING C -
ROTC/POWELL

Job No.
D-SAN-1003-01
Drawn By:
CV
Designed By:
CV
Date:
04/29/2026

Sheet No.
T104

Autosave Docs\\CRUX-San Angelo ISD Paging System Upgrade\\D-SAN-1003-01 SASD-103_Paging Upgrade_Tech_02\\HOSTED.rvt

SHEET NOTES:

REFERENCE SHEET TG101 FOR ALL SYMBOLS AND PROJECT SPECIFIC NOTES.

EXISTING PAGING SPEAKERS (S1) ARE SHOWN IN HALF-TONE. CONTRACTOR SHALL REMOVE EXISTING PAGING SPEAKERS (S1) AND REPLACE WITH CEILING TILE OR BLANK COVER PLATE, UNO.

ALL CONDUITS SHALL BE 1" FOR ALL DEVICES UNLESS NOTED OTHERWISE ON THE TECHNOLOGY DRAWINGS.

IN AREAS WITH CONCRETE OR MASONRY WALLS, CONTRACTOR SHALL PROVIDE SURFACE RACEWAY SYSTEM.

IN AREAS WITH EXPOSED CEILINGS, CONTRACTOR SHALL INSTALL ALL CABLING IN CONDUIT. CONTRACTOR TO PERFORM PAINT FINISH AS COORDINATED WITH OWNER.

CONTRACTOR SHALL DEMOLISH ANY UNUSED CABLING BACK TO ITS ORIGIN AND DISPOSE.


CONTRACTOR SHALL REPLACE ALL EXISTING PTT BUTTONS PRESENT IN THE FACILITY WITH A BLANK COVER PLATE. CONTRACTOR SHALL LOCATE, DOCUMENT AND REMEDIATE IN THE SAME METHOD ANY PTT BUTTON NOT EXPLICITLY SHOWN IN THIS DRAWING SET.

CONTRACTOR IS RESPONSIBLE FOR PROVIDING LIFT FOR ALL HIGH CEILING AREAS (FINE ARTS, GYM, ETC.). CONTRACTOR SHALL ALSO BE REQUIRED TO PROVIDE FLOORING PROTECTION.

KEYNOTE LEGEND


(NOT ALL KEYNOTES MAY APPLY.)

01. EXISTING, CONTRACTOR SHALL REPLACE WITH NEW DEVICE AND NEW CABLING. CEILING TILE MAY REMAIN IN PLACE UNLESS DAMAGED.
02. EXISTING, TO REMAIN. CONTRACTOR SHALL INSTALL BRIDGE FROM ANALOG SPEAKER TO IP HEAD END.
03. CONTRACTOR SHALL COMPLETELY REMOVE ALL ABANDONED ANALOG SPEAKER WIRING AND SUPPORTING TERMINAL BLOCKS FROM THE FACILITY. TERMINAL BLOCKS THAT SUPPORT OTHER EXISTING DEVICES SHALL REMAIN.
04. INSTALL PLASTIC 1/2" RACEWAY FOR PATCH CABLE TO TOP OF SURFACE MOUNTED CLOCK BACK BOX. TERMINATE DATA ABOVE CEILING.
05. EXISTING, CONTRACTOR SHALL REMOVE DEVICE, DEMOLISH CABLING BACK TO ITS ORIGIN, AND INSTALL NEW BLANK FACEPLATE.
06. INSTALL DATA IN ADJACENT OVERHEAD CEILING SPACE. PROVIDE 1" SLEEVE THROUGH CMU WALL TO BACK OF CLOCK DISPLAY.
07. SURFACE MOUNTED CONDUIT NEEDED FOR ALL NEW PAGING AND RELATED DEVICES.
08. PROVIDE 1" CONDUIT TO TOP OF SURFACE MOUNTED CLOCK BACK BOX FOR PATCH CABLE. DATA SHALL BE TERMINATED ABOVE CEILING.
09. INSTALL SURFACE MOUNTED RACEWAY FROM DEVICE BACK TO TECH CLOSET LOCATION.
10. CEILING SPEAKER IN CAN MOUNTED TO STRUCTURAL STEEL.
11. THIS IS A PLASTER CEILING, CONDUIT OR PLASTIC RACEWAY WILL NEED TO BE SECURED TO THE CEILING ITSELF.
12. SPEAKERS MOUNTED TO STRUCTURAL STEEL.
13. INSTALL SURFACE RACEWAY FOR ENTIRE PATH FROM TC TO DEVICE.
14. EXISTING SPEAKER BUILT FLUSH IN WALL. DO NOT REMOVE. INSTALL NEW DEVICE ADJACENT TO EXISTING. INSTALL DATA DROP IN ACCESSIBLE CEILING IN ADJACENT SPACE.
15. REMOVE EXISTING HORNS AND LEAVE MOUNTS INTACT, REMOVE EXISTING CABLING. INSTALL NEW DUAL SIDED DEVICE ADJACENT TO FORMER HORN LOCATION. INSTALL DATA IN ADJACENT CEILING SPACE.
16. REFERENCE DIV 27 FOR RACK INFORMATION AND ALLOWANCE REQUIREMENTS. FINAL LOCATIONS TO BE COORDINATED WITH OWNER PRIOR TO INSTALLATION.
17. NOT USED.
18. RECENTLY INSTALLED SPEAKER, REMOVE, PROTECT, AND REDEPLOY WHERE OTHER NEW ANALOG CEILING SPEAKERS ARE NEEDED.
19. J-BOX LARGER THAN 4X4" NEEDED HERE. PROVIDE ADDITIONAL SLACK FOR FUTURE RETERMINATIONS.
20. FIELD CONDITIONS MAY DIFFER FROM WHAT IS SHOWN. COORDINATE EXACT LOCATION WITH OWNER.
21. GYP CEILING. CONTRACTOR SHALL ACCOUNT FOR THREE (3) 24"x24" ACCESS PANEL LOCATIONS IN PRICING. VERIFY PATHWAYS ON SITE.

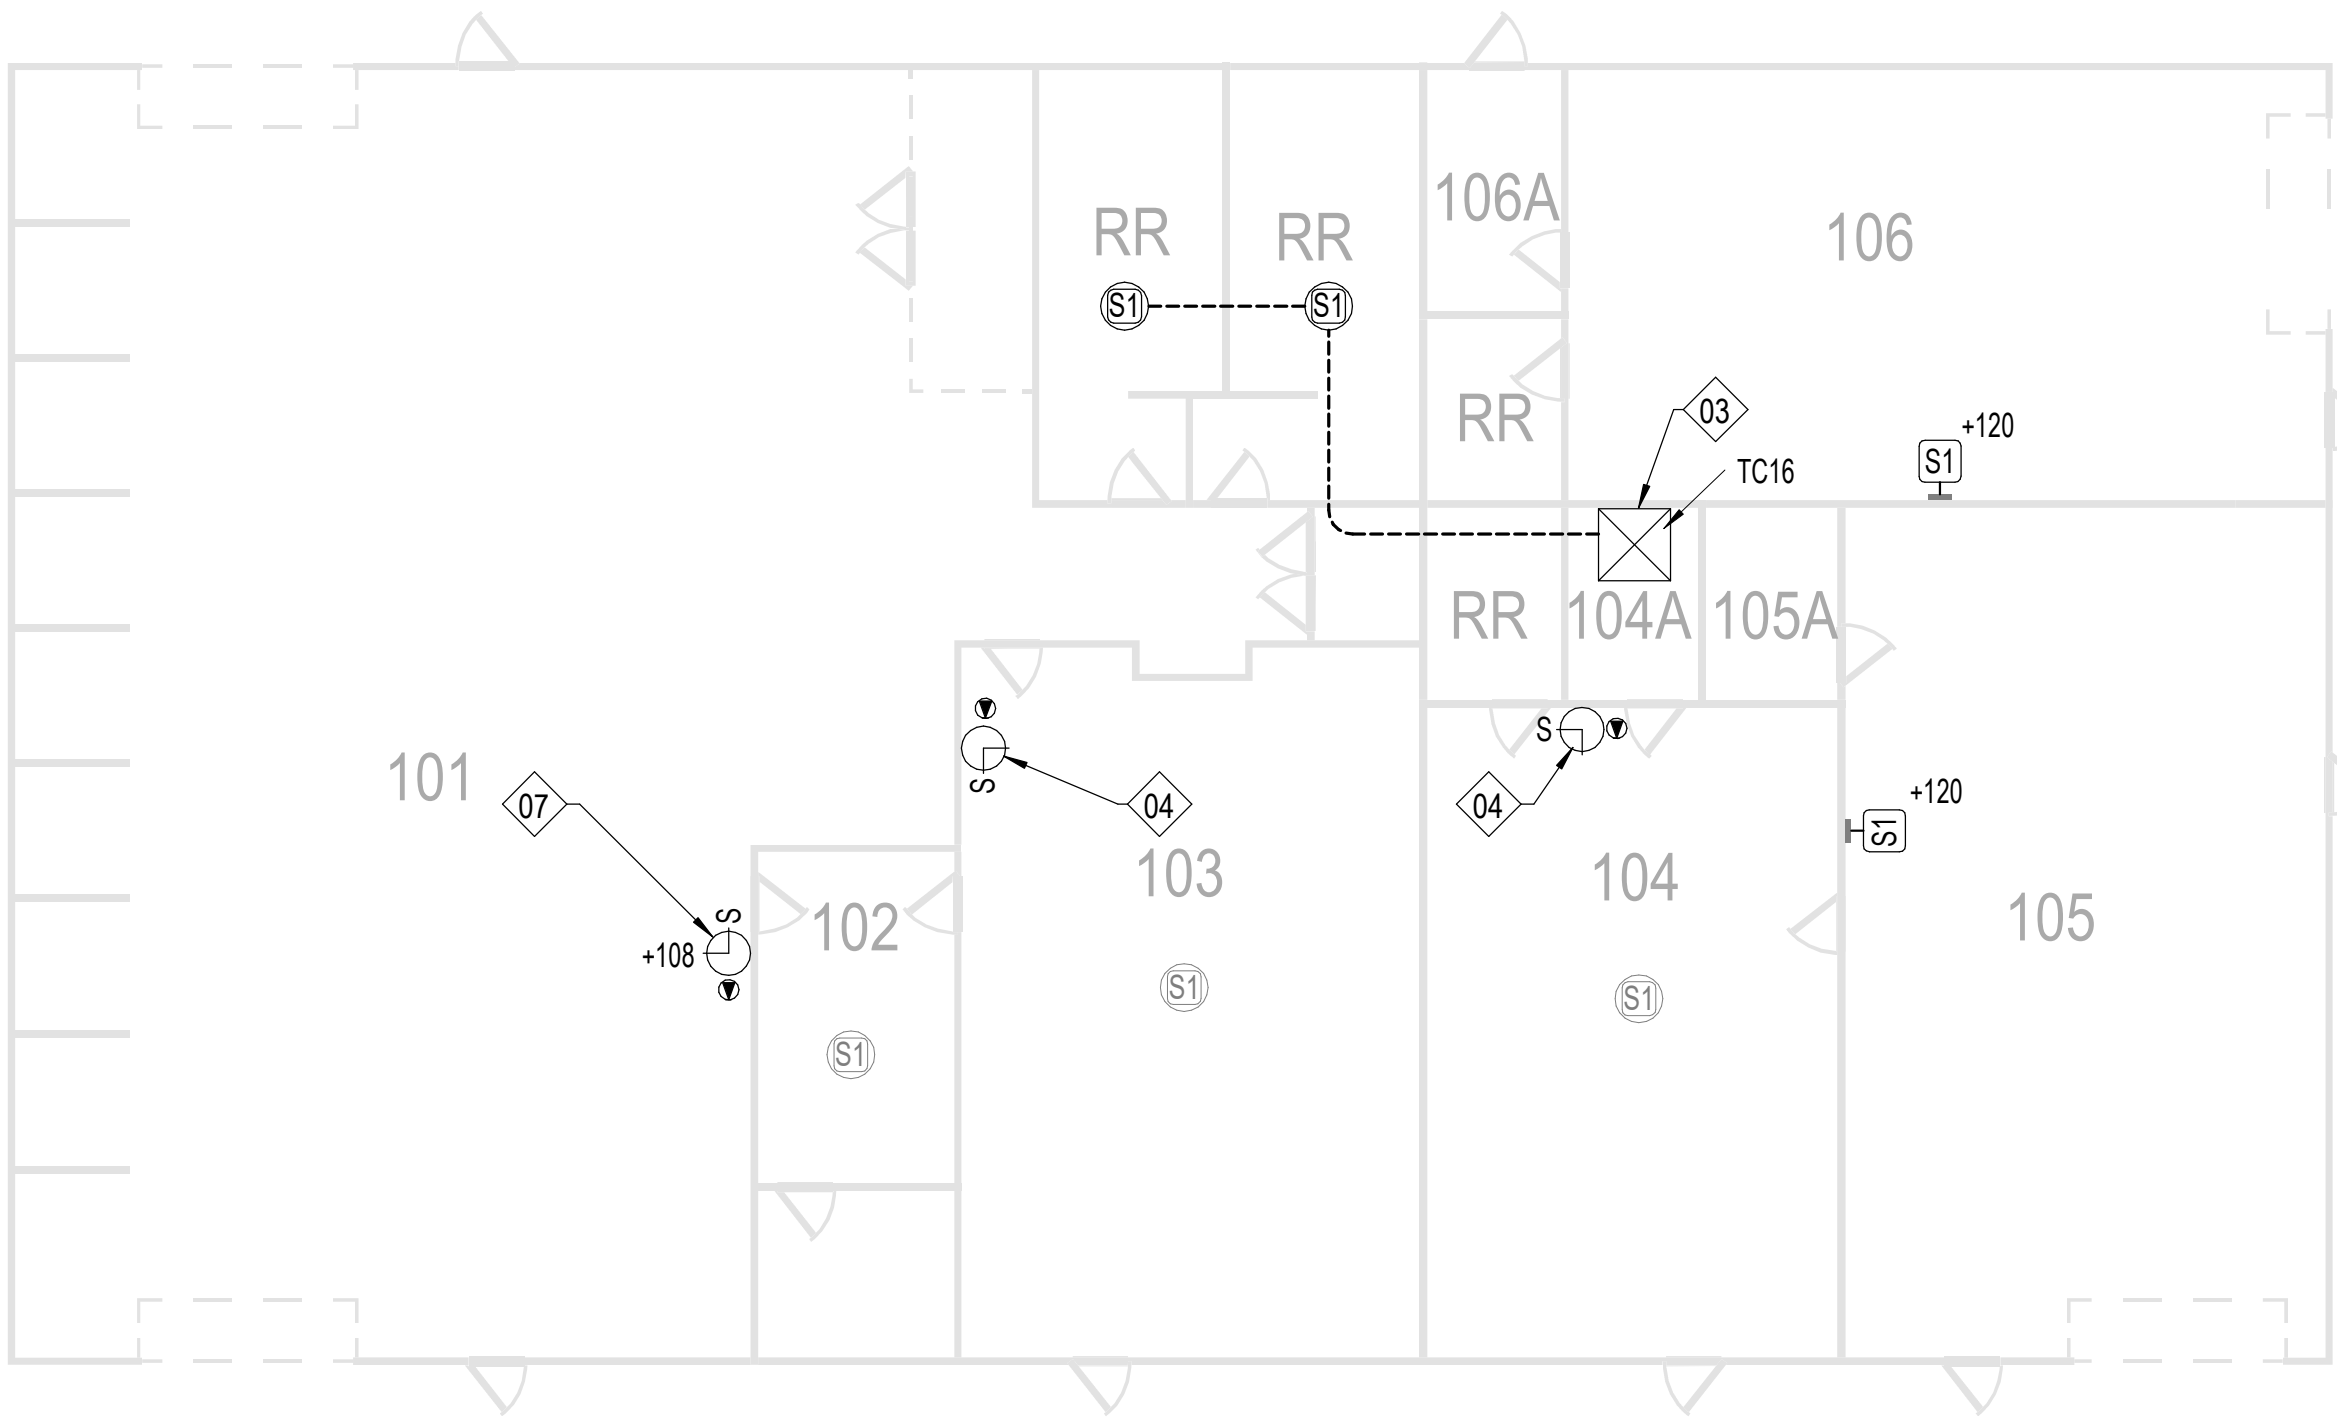

SAN ANGELO ISD
PAGING UPGRADE
SAN ANGELO, TEXAS
D-SAN-1003-01

Project:

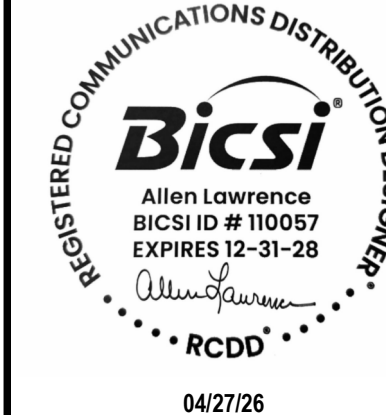

FLOOR PLAN - CENTRAL
HS - BUILDING D - KELTON
AG

Job No:
D-SAN-1003-01


Drawn By:
CV

Designed By:
CV

Date:
04/29/2026

Sheet No:

T105

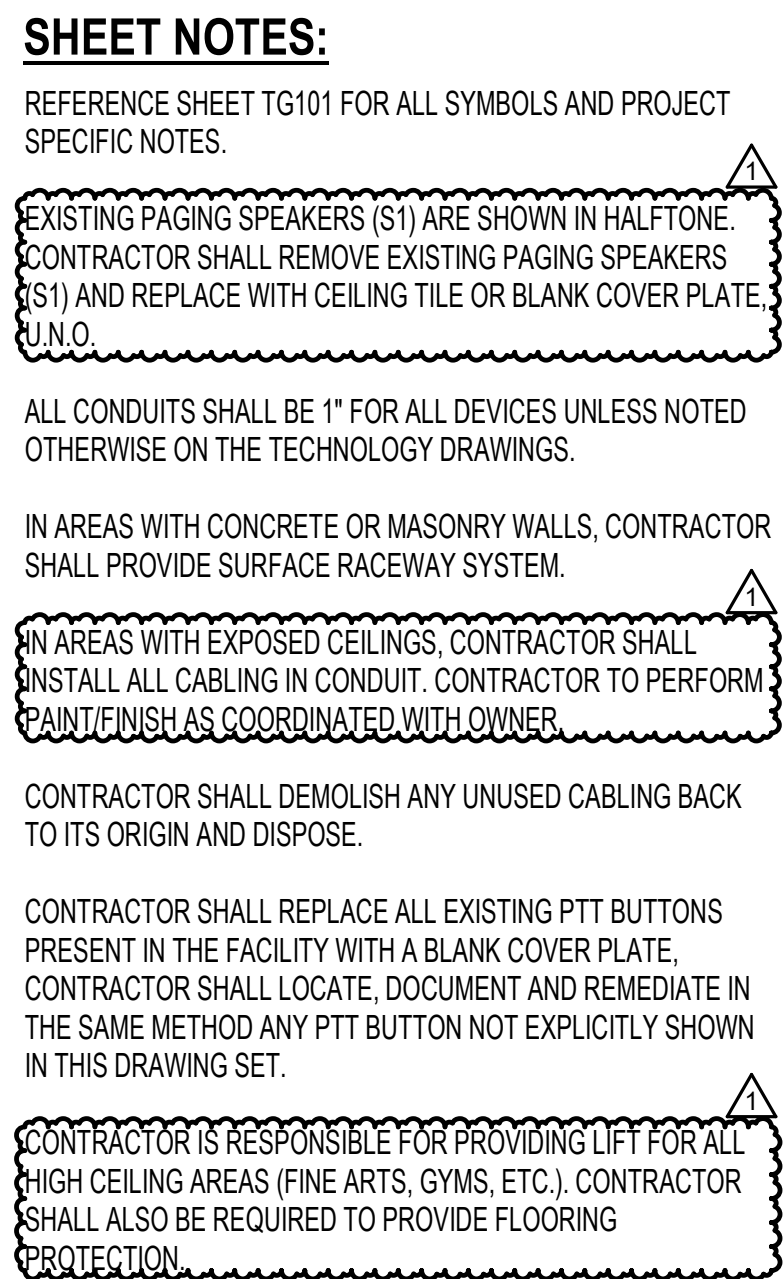

(NOT ALL KEYNOTES MAY APPLY)

01. EXISTING CONTRACTOR SHALL REPLACE WITH NEW DEVICE AND NEW CABLING. CEILING TILE MAY REMAIN IN PLACE UNLESS DAMAGED.
02. EXISTING, TO REMAIN. CONTRACTOR SHALL INSTALL BRIDGE FROM ANALOG SPEAKER TO IP HEAD END.
03. CONTRACTOR SHALL COMPLETELY REMOVE ALL ABANDONED ANALOG SPEAKER WIRING AND SUPPORTING TERMINAL BLOCKS FROM THE FACILITY. TERMINAL BLOCKS THAT SUPPORT OTHER EXISTING DEVICES SHALL REMAIN.
04. INSTALL PLASTIC 1/2" RACEWAY FOR PATCH CABLE TO TOP OF SURFACE MOUNTED CLOCK BACK BOX. TERMINATE DATA ABOVE CEILING.
05. EXISTING; CONTRACTOR SHALL REMOVE DEVICE. DEMOLISH CABLING BACK TO ITS ORIGIN, AND INSTALL NEW BLANK FACEPLATE.
06. INSTALL DATA IN ADJACENT OVERHEAD CEILING SPACE. PROVIDE 1" SLEEVE THROUGH CMU WALL TO BACK OF CLOCK DISPLAY.
07. SURFACE MOUNTED CONDUIT NEEDED FOR ALL NEW PAGING AND RELATED DEVICES.
08. PROVIDE 1" CONDUIT TO TOP OF SURFACE MOUNTED CLOCK BACK BOX FOR PATCH CABLE. DATA SHALL BE TERMINATED ABOVE CEILING.
09. INSTALL SURFACE MOUNTED RACEWAY FROM DEVICE BACK TO TECH CLOSET LOCATION.
10. CEILING SPEAKER IN CAN MOUNTED TO STRUCTURAL STEEL.
11. THIS IS A PLASTER CEILING, CONDUIT OR PLASTIC RACEWAY WILL NEED TO BE SECURED TO THE CEILING ITSELF.
12. SPEAKERS MOUNTED TO STRUCTURAL STEEL.
13. INSTALL SURFACE RACEWAY FOR ENTIRE PATH FROM TC TO DEVICE.
14. EXISTING SPEAKER BUILT IN FLUSH IN WALL. DO NOT REMOVE. INSTALL NEW DEVICE ADJACENT TO EXISTING. INSTALL DATA DROP IN ACCESSIBLE CEILING IN ADJACENT SPACE.
15. REMOVE EXISTING HORNS AND LEAVE MOUNTS INTACT, REMOVE EXISTING CABLING. INSTALL NEW DUAL SIZED DEVICE ADJACENT TO FORMER HORN LOCATION. INSTALL DATA IN ADJACENT CEILING SPACE.
16. REFERENCE DIV 27 FOR BACK INFORMATION AND ALLOWANCE REQUIREMENTS. FINAL LOCATIONS TO BE COORDINATED WITH OWNER PRIOR TO INSTALLATION.
17. NOT USED.
18. RECENTLY INSTALLED SPEAKER. REMOVE, PROTECT, AND REDEPLOY WHERE OTHER NEW ANALOG CEILING SPEAKERS ARE NEEDED.
19. J-BOX LARGER THAN 4X4" NEEDED HERE. PROVIDE ADDITIONAL SLACK FOR FUTURE RETERMINATIONS.
20. FIELD CONDITIONS MAY DIFFER FROM WHAT IS SHOWN. COORDINATE EXACT LOCATION WITH OWNER.
21. GYP CEILING. CONTRACTOR SHALL ACCOUNT FOR THREE (3) 2'X4'X4" ACCESS PANEL LOCATIONS IN PRICING. VERIFY PATHWAYS ON SITE.

16. REFERENCE DIV 27 FOR RACK INFORMATION AND ALLOWANCE REQUIREMENTS. FINAL LOCATIONS TO BE COORDINATED WITH OWNER PRIOR TO INSTALLATION.

17. NOT USED.

18. RECENTLY INSTALLED SPEAKER. REMOVE, PROTECT, AND REDEPLOY WHERE OTHER NEW ANALOG CEILING SPEAKERS ARE NEEDED.

19. J-BOX LARGER THAN 4X4" NEEDED HERE. PROVIDE ADDITIONAL SLACK FOR FUTURE RETERMINATIONS.

20. FIELD CONDITIONS MAY DIFFER FROM WHAT IS SHOWN.
COORDINATE EXACT LOCATION WITH OWNER.

21. GYP CEILING. CONTRACTOR SHALL ACCOUNT FOR THREE (3) 24"X24" ACCESS PANEL LOCATIONS IN PRICING. VERIFY PATHWAYS ON SITE.

lendum 01

Date: 05/18/26

1

Project:



CRUX
TECHNOLOGY + SECURITY SOLUTIONS
800.685.6440
www.cruxsolutions.com

FLOOR PLAN - CENTRAL
HS - BUILDING E - SMITH
GYM

Job. No.
D-SAN-1003-01

Drawn By:
CV


Designed By:
CV

Date:
04/29/2026

Sheet No. _____

T106

Autodesk Docs\CRUX-San Angelo ISD Paging System Upgrade\B SAN-1003-01 SANSD HS Paging Upgrade, TECH, 02\HOSTED.rvt

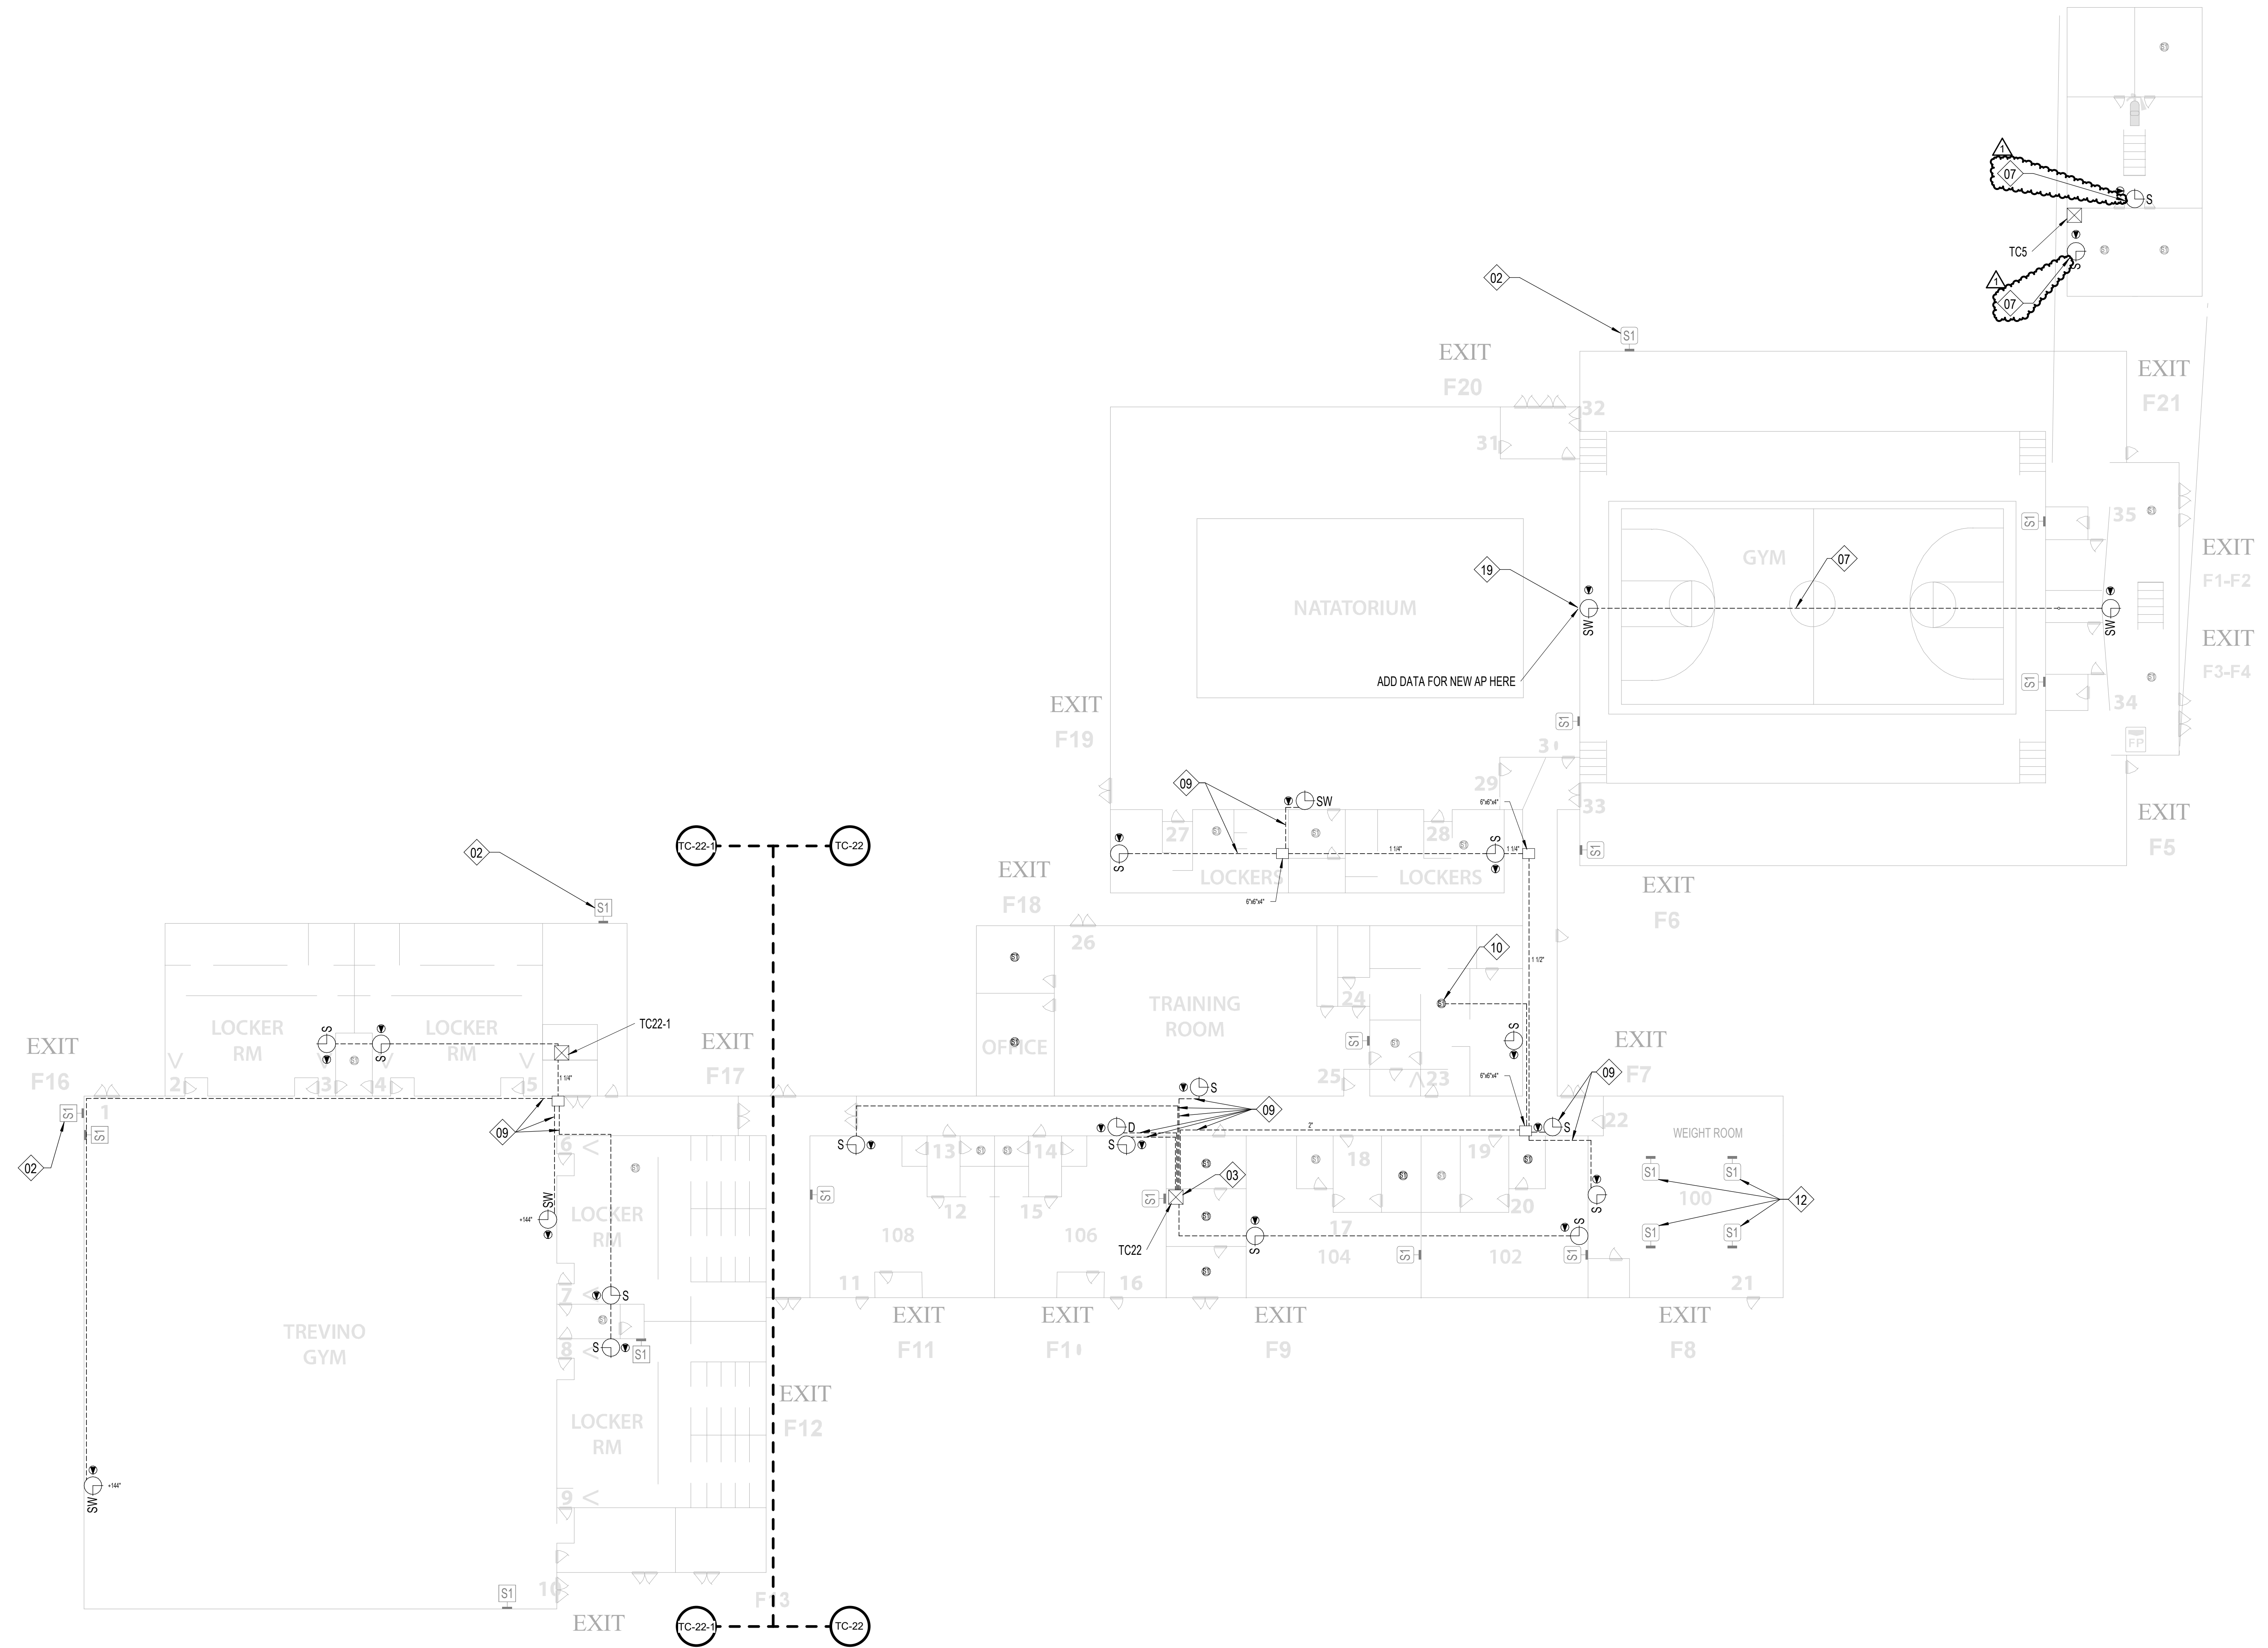

1 FLOOR PLAN - CENTRAL HS - BUILDING F - DEDRICKSON AND TREVINO
T107 1/16" = 1'-0"

SHEET NOTES:

REFERENCE SHEET TG101 FOR ALL SYMBOLS AND PROJECT SPECIFIC NOTES.

EXISTING PAGING SPEAKERS (S1) ARE SHOWN IN HALF-TONE. CONTRACTOR SHALL REMOVE EXISTING PAGING SPEAKERS (S1) AND REPLACE WITH CEILING TILE OR BLANK COVER PLATE, UNO.

ALL CONDUITS SHALL BE 1" FOR ALL DEVICES UNLESS NOTED OTHERWISE ON THE TECHNOLOGY DRAWINGS.

IN AREAS WITH CONCRETE OR MASONRY WALLS, CONTRACTOR SHALL PROVIDE SURFACE RACEWAY SYSTEM.

IN AREAS WITH EXPOSED CEILINGS, CONTRACTOR SHALL INSTALL ALL CABLING IN CONDUIT. CONTRACTOR TO PERFORM PAINT FINISH AS COORDINATED WITH OWNER.

CONTRACTOR SHALL DEMOLISH ANY UNUSED CABLING BACK TO ITS ORIGIN AND DISPOSE.

CONTRACTOR SHALL REPLACE ALL EXISTING PTT BUTTONS PRESENT IN THE FACILITY WITH A BLANK COVER PLATE. CONTRACTOR SHALL LOCATE, DOCUMENT AND REMEDIATE IN THE SAME METHOD ANY PTT BUTTON NOT EXPLICITLY SHOWN IN THIS DRAWING SET.

CONTRACTOR IS RESPONSIBLE FOR PROVIDING LIFT FOR ALL HIGH CEILING AREAS (FINE ARTS, GYMS, ETC.). CONTRACTOR SHALL ALSO BE REQUIRED TO PROVIDE FLOORING PROTECTION.

KEYNOTE LEGEND

(NOT ALL KEYNOTES MAY APPLY)

01. EXISTING, CONTRACTOR SHALL REPLACE WITH NEW DEVICE AND NEW CABLING. CEILING TILE MAY REMAIN IN PLACE UNLESS DAMAGED.

02. EXISTING, TO REMAIN. CONTRACTOR SHALL INSTALL BRIDGE FROM ANALOG SPEAKER TO IP HEAD END.

03. CONTRACTOR SHALL COMPLETELY REMOVE ALL ABANDONED ANALOG SPEAKER WIRING AND SUPPORTING TERMINAL BLOCKS FROM THE FACILITY. TERMINATE DATA THAT SUPPORT OTHER EXISTING DEVICES SHALL REMAIN.

04. INSTALL PLASTIC 1/2" RACEWAY FOR PATCH CABLE TO TOP OF SURFACE MOUNTED CLOCK BACK BOX. TERMINATE DATA ABOVE CEILING.

05. EXISTING, CONTRACTOR SHALL REMOVE DEVICE, DEMOLISH CABLING BACK TO ITS ORIGIN, AND INSTALL NEW BLANK FACEPLATE.

06. INSTALL DATA IN ADJACENT OVERHEAD CEILING SPACE. PROVIDE 1" SLEEVE THROUGH CMU WALL TO BACK OF CLOCK DISPLAY.

07. SURFACE MOUNTED CONDUIT NEEDED FOR ALL NEW PAGING AND RELATED DEVICES.

08. PROVIDE 1" CONDUIT TO TOP OF SURFACE MOUNTED CLOCK BACK BOX FOR PATCH CABLE. DATA SHALL BE TERMINATED ABOVE CEILING.

09. INSTALL SURFACE MOUNTED RACEWAY FROM DEVICE BACK TO TECH CLOSET LOCATION.

10. CEILING SPEAKER IN CAN MOUNTED TO STRUCTURAL STEEL.

11. THIS IS A PLASTER CEILING, CONDUIT OR PLASTIC RACEWAY WILL NEED TO BE SECURED TO THE CEILING ITSELF.

12. SPEAKERS MOUNTED TO STRUCTURAL STEEL.

13. INSTALL SURFACE RACEWAY FOR ENTIRE PATH FROM TC TO DEVICE.

14. EXISTING SPEAKER BUILT FLUSH IN WALL. DO NOT REMOVE. INSTALL NEW DEVICE ADJACENT TO EXISTING. INSTALL DATA DROP IN ACCESSIBLE CEILING IN ADJACENT SPACE.

15. REMOVE EXISTING HORNS AND LEAVE MOUNTS INTACT. REMOVE EXISTING CABLING. INSTALL NEW DUAL SIDED DEVICE ADJACENT TO FORMER HORN LOCATION. INSTALL DATA IN ADJACENT CEILING SPACE.

16. REFERENCE DIV 27 FOR RACK INFORMATION AND ALLOWANCE REQUIREMENTS. FINAL LOCATIONS TO BE COORDINATED WITH OWNER PRIOR TO INSTALLATION.

17. NOT USED.

18. RECENTLY INSTALLED SPEAKER, REMOVE, PROTECT, AND REDEPLOY WHERE OTHER NEW ANALOG CEILING SPEAKERS ARE NEEDED.

19. J-BOX LARGER THAN 4X4" NEEDED HERE. PROVIDE ADDITIONAL SLACK FOR FUTURE RETERMINATIONS.

20. FIELD CONDITIONS MAY DIFFER FROM WHAT IS SHOWN. COORDINATE EXACT LOCATION WITH OWNER.

21. GYP CEILING. CONTRACTOR SHALL ACCOUNT FOR THREE (3) 24"x24" ACCESS PANEL LOCATIONS IN PRICING. VERIFY PATHWAYS ON SITE.

Description

Addendum 01

Date: 05/18/25

Revision: 1

SAN ANGELO ISD
PAGING UPGRADE
SAN ANGELO, TEXAS
D-SAN-1003-01

Project:



FLOOR PLAN - CENTRAL
HS - BUILDING F -
DEDRICKSON AND
TREVINO

Job. No.
D-SAN-1003-01

Drawn By:
CV


Designed By:
CV

Date:
04/29/2025

Sheet No.

T107

Autosave Docs:CRUX-San Angelo ISD Paging System UpgradeD:\SAN-1003-01 SANSD ISD Paging Upgrade, TECH, 025(POSTED).rvt

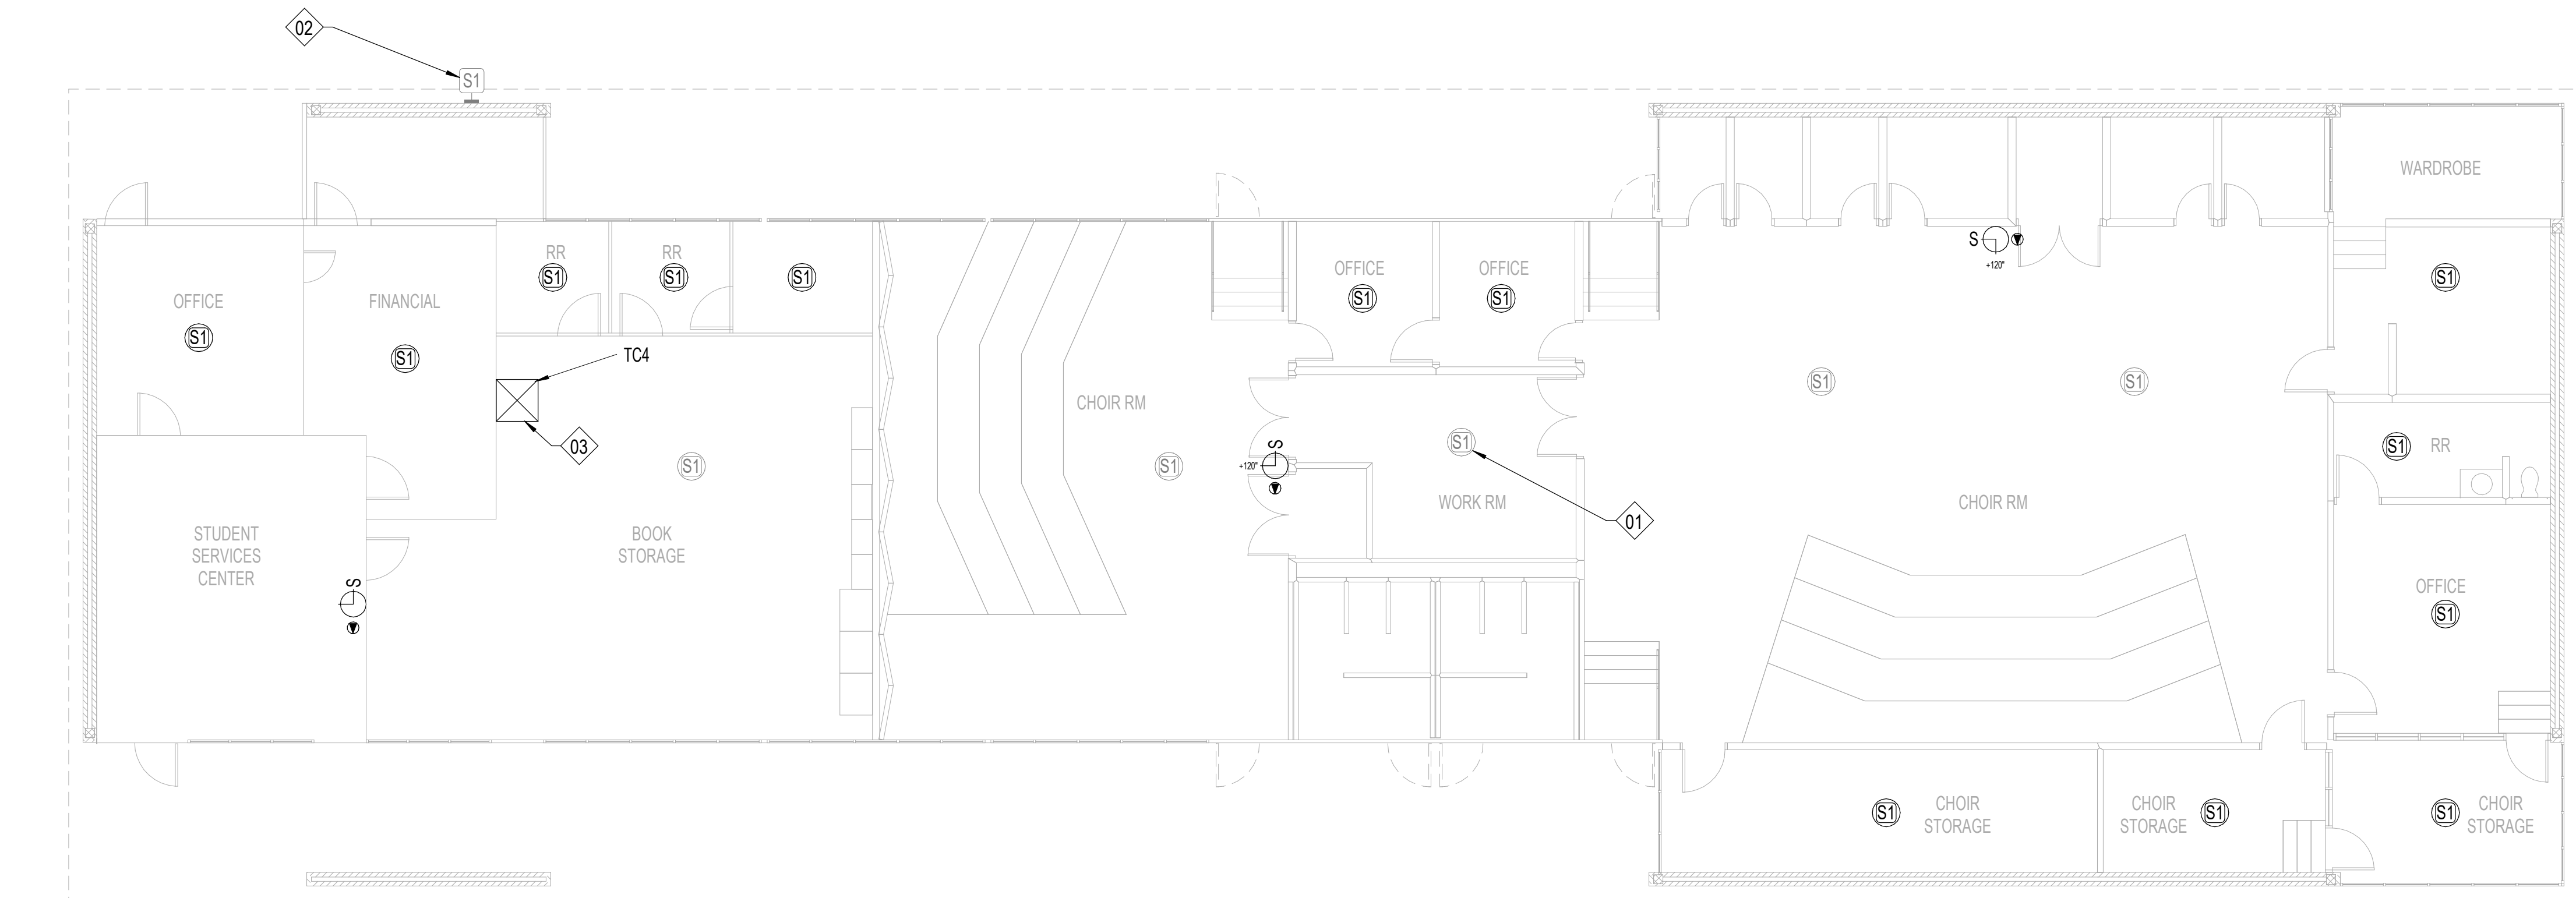

1 FLOOR PLAN - CENTRAL HS - BUILDING G - MICHELANGELO - STUDENT SERVICES/FINE ARTS
T108 1/8" = 1'-0"

SHEET NOTES:

REFERENCE SHEET TG101 FOR ALL SYMBOLS AND PROJECT SPECIFIC NOTES.

EXISTING PAGING SPEAKERS (S1) ARE SHOWN IN HALF-TONE. CONTRACTOR SHALL REMOVE EXISTING PAGING SPEAKERS (S1) AND REPLACE WITH CEILING TILE OR BLANK COVER PLATE, UNO.

ALL CONDUITS SHALL BE 1" FOR ALL DEVICES UNLESS NOTED OTHERWISE ON THE TECHNOLOGY DRAWINGS.

IN AREAS WITH CONCRETE OR MASONRY WALLS, CONTRACTOR SHALL PROVIDE SURFACE RACEWAY SYSTEM.

IN AREAS WITH EXPOSED CEILINGS, CONTRACTOR SHALL INSTALL ALL CABLING IN CONDUIT. CONTRACTOR TO PERFORM PAINT FINISH AS COORDINATED WITH OWNER.

CONTRACTOR SHALL DEMOLISH ANY UNUSED CABLING BACK TO ITS ORIGIN AND DISPOSE.

CONTRACTOR SHALL REPLACE ALL EXISTING PTT BUTTONS PRESENT IN THE FACILITY WITH A BLANK COVER PLATE. CONTRACTOR SHALL LOCATE, DOCUMENT AND REMEDIATE IN THE SAME METHOD ANY PTT BUTTON NOT EXPLICITLY SHOWN IN THIS DRAWING SET.

CONTRACTOR IS RESPONSIBLE FOR PROVIDING LIFT FOR ALL HIGH CEILING AREAS (FINE ARTS, GYM, ETC.). CONTRACTOR SHALL ALSO BE REQUIRED TO PROVIDE FLOORING PROTECTION.

KEYNOTE LEGEND

(NOT ALL KEYNOTES MAY APPLY.)

01. EXISTING, CONTRACTOR SHALL REPLACE WITH NEW DEVICE AND NEW CABLING. CEILING TILE MAY REMAIN IN PLACE UNLESS DAMAGED.
02. EXISTING, TO REMAIN. CONTRACTOR SHALL INSTALL BRIDGE FROM ANALOG SPEAKER TO IP HEAD END.
03. CONTRACTOR SHALL COMPLETELY REMOVE ALL ABANDONED ANALOG SPEAKER WIRING AND SUPPORTING TERMINAL BLOCKS FROM THE FACILITY. TERMINAL BLOCKS THAT SUPPORT OTHER EXISTING DEVICES SHALL REMAIN.
04. INSTALL PLASTIC 1/2" RACEWAY FOR PATCH CABLE TO TOP OF SURFACE MOUNTED CLOCK BACK BOX. TERMINATE DATA ABOVE CEILING.
05. EXISTING, CONTRACTOR SHALL REMOVE DEVICE, DEMOLISH CABLING BACK TO ITS ORIGIN, AND INSTALL NEW BLANK FACEPLATE.
06. INSTALL DATA IN ADJACENT OVERHEAD CEILING SPACE. PROVIDE 1" SLEEVE THROUGH CMU WALL TO BACK OF CLOCK DISPLAY.
07. SURFACE MOUNTED CONDUIT NEEDED FOR ALL NEW PAGING AND RELATED DEVICES.
08. PROVIDE 1" CONDUIT TO TOP OF SURFACE MOUNTED CLOCK BACK BOX FOR PATCH CABLE. DATA SHALL BE TERMINATED ABOVE CEILING.
09. INSTALL SURFACE MOUNTED RACEWAY FROM DEVICE BACK TO TECH CLOSET LOCATION.
10. CEILING SPEAKER IN CAN MOUNTED TO STRUCTURAL STEEL.
11. THIS IS A PLASTER CEILING, CONDUIT OR PLASTIC RACEWAY WILL NEED TO BE SECURED TO THE CEILING ITSELF.
12. SPEAKERS MOUNTED TO STRUCTURAL STEEL.
13. INSTALL SURFACE RACEWAY FOR ENTIRE PATH FROM TC TO DEVICE.
14. EXISTING SPEAKER BUILT FLUSH IN WALL. DO NOT REMOVE. INSTALL NEW DEVICE ADJACENT TO EXISTING. INSTALL DATA DROP IN ACCESSIBLE CEILING IN ADJACENT SPACE.
15. REMOVE EXISTING HORNS AND LEAVE MOUNTS INTACT, REMOVE EXISTING CABLING. INSTALL NEW DUAL SIDED DEVICE ADJACENT TO FORMER HORN LOCATION. INSTALL DATA IN ADJACENT CEILING SPACE.
16. REFERENCE DIV 27 FOR RACK INFORMATION AND ALLOWANCE REQUIREMENTS. FINAL LOCATIONS TO BE COORDINATED WITH OWNER PRIOR TO INSTALLATION.
17. NOT USED.
18. RECENTLY INSTALLED SPEAKER, REMOVE, PROTECT, AND REDEPLOY WHERE OTHER NEW ANALOG CEILING SPEAKERS ARE NEEDED.
19. J-BOX LARGER THAN 4X4" NEEDED HERE. PROVIDE ADDITIONAL SLACK FOR FUTURE RETERMINATIONS.
20. FIELD CONDITIONS MAY DIFFER FROM WHAT IS SHOWN. COORDINATE EXACT LOCATION WITH OWNER.
21. GYP CEILING. CONTRACTOR SHALL ACCOUNT FOR THREE (3) 24"X24" ACCESS PANEL LOCATIONS IN PRICING. VERIFY PATHWAYS ON SITE.

Description

Date

Revision

Project

SAN ANGELO ISD
PAGING UPGRADE
SAN ANGELO, TEXAS
D-SAN-1003-01



FLOOR PLAN - CENTRAL
HS - BUILDING G -
MICHELANGELO


Job No.
D-SAN-1003-01
Drawn By:
CV
Designed By:
CV
Date:
04/29/2026

Sheet No.

T108

Autosave Docs\\CRUX\\San Angelo ISD Paging System Upgrade\\D-SAN-1003-01 SANSD ISD Paging Upgrade, TECH, 02\\HOSTED.rvt

1 FLOOR PLAN - CENTRAL HS - BUILDING H - TENNIS BUILDING
T109 1/8" = 1'-0"

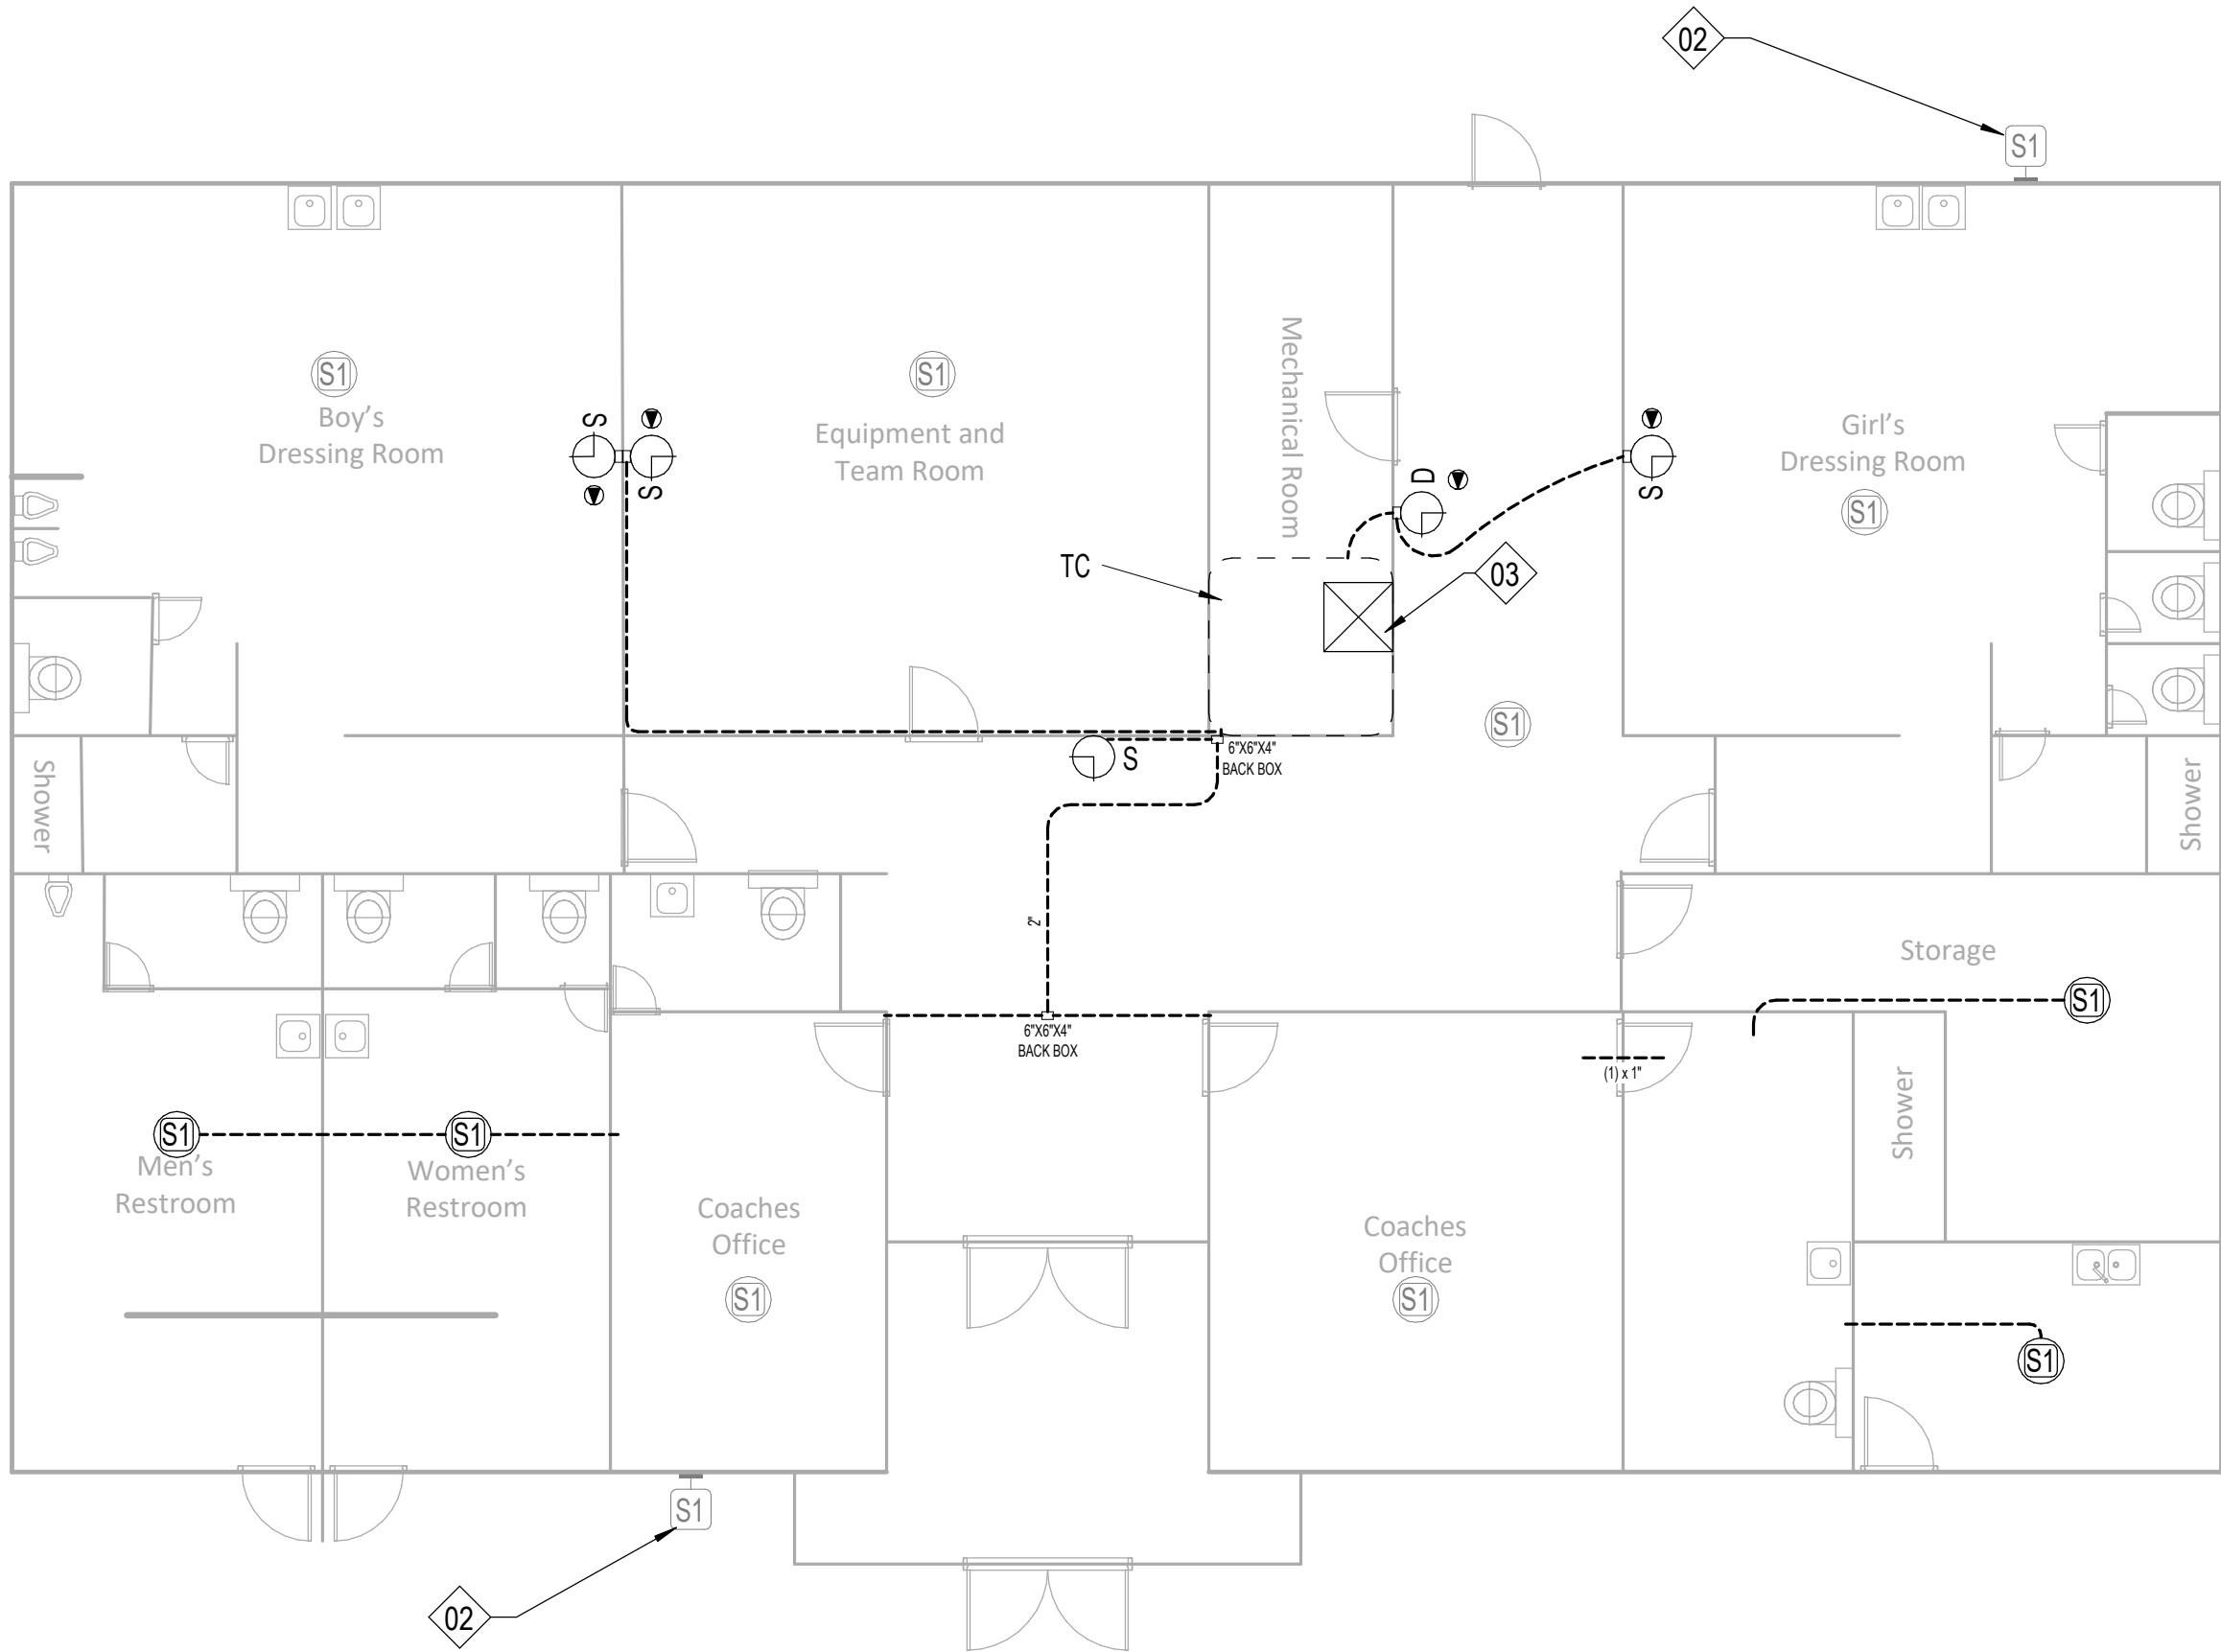

SHEET NOTES:

REFERENCE SHEET TG101 FOR ALL SYMBOLS AND PROJECT SPECIFIC NOTES.

EXISTING PAGING SPEAKERS (S1) ARE SHOWN IN HALF-TONE. CONTRACTOR SHALL REMOVE EXISTING PAGING SPEAKERS (S1) AND REPLACE WITH CEILING TILE OR BLANK COVER PLATE, UNLESS NOTED OTHERWISE ON THE TECHNOLOGY DRAWINGS.

IN AREAS WITH CONCRETE OR MASONRY WALLS, CONTRACTOR SHALL PROVIDE SURFACE RACEWAY SYSTEM.

IN AREAS WITH EXPOSED CEILINGS, CONTRACTOR SHALL INSTALL ALL CABLING IN CONDUIT. CONTRACTOR TO PERFORM PAINT FINISH AS COORDINATED WITH OWNER.

CONTRACTOR SHALL DEMOLISH ANY UNUSED CABLING BACK TO ITS ORIGIN AND DISPOSE.

CONTRACTOR SHALL REPLACE ALL EXISTING PTT BUTTONS PRESENT IN THE FACILITY WITH A BLANK COVER PLATE. CONTRACTOR SHALL LOCATE, DOCUMENT AND REMEDIATE IN THE SAME METHOD ANY PTT BUTTON NOT EXPLICITLY SHOWN IN THIS DRAWING SET.

CONTRACTOR IS RESPONSIBLE FOR PROVIDING LIFT FOR ALL HIGH CEILING AREAS (FINE ARTS, GYM, ETC.). CONTRACTOR SHALL ALSO BE REQUIRED TO PROVIDE FLOORING PROTECTION.

KEYNOTE LEGEND

(NOT ALL KEYNOTES MAY APPLY.)

01. EXISTING, CONTRACTOR SHALL REPLACE WITH NEW DEVICE AND NEW CABLING. CEILING TILE MAY REMAIN IN PLACE UNLESS DAMAGED.
02. EXISTING, TO REMAIN. CONTRACTOR SHALL INSTALL BRIDGE FROM ANALOG SPEAKER TO IP HEAD END.
03. CONTRACTOR SHALL COMPLETELY REMOVE ALL ABANDONED ANALOG SPEAKER WIRING AND SUPPORTING TERMINAL BLOCKS FROM THE FACILITY. TERMINAL BLOCKS THAT SUPPORT OTHER EXISTING DEVICES SHALL REMAIN.
04. INSTALL PLASTIC 1/2" RACEWAY FOR PATCH CABLE TO TOP OF SURFACE MOUNTED CLOCK BACK BOX. TERMINATE DATA ABOVE CEILING.
05. EXISTING, CONTRACTOR SHALL REMOVE DEVICE, DEMOLISH CABLING BACK TO ITS ORIGIN, AND INSTALL NEW BLANK FACEPLATE.
06. INSTALL DATA IN ADJACENT OVERHEAD CEILING SPACE. PROVIDE 1" SLEEVE THROUGH CMU WALL TO BACK OF CLOCK DISPLAY.
07. SURFACE MOUNTED CONDUIT NEEDED FOR ALL NEW PAGING AND RELATED DEVICES.
08. PROVIDE 1" CONDUIT TO TOP OF SURFACE MOUNTED CLOCK BACK BOX FOR PATCH CABLE. DATA SHALL BE TERMINATED ABOVE CEILING.
09. INSTALL SURFACE MOUNTED RACEWAY FROM DEVICE BACK TO TECH CLOSET LOCATION.
10. CEILING SPEAKER IN CAN MOUNTED TO STRUCTURAL STEEL.
11. THIS IS A PLASTER CEILING, CONDUIT OR PLASTIC RACEWAY WILL NEED TO BE SECURED TO THE CEILING ITSELF.
12. SPEAKERS MOUNTED TO STRUCTURAL STEEL.
13. INSTALL SURFACE RACEWAY FOR ENTIRE PATH FROM TC TO DEVICE.
14. EXISTING SPEAKER BUILT FLUSH IN WALL. DO NOT REMOVE. INSTALL NEW DEVICE ADJACENT TO EXISTING. INSTALL DATA DROP IN ACCESSIBLE CEILING IN ADJACENT SPACE.
15. REMOVE EXISTING HORNS AND LEAVE MOUNTS INTACT, REMOVE EXISTING CABLING. INSTALL NEW DUAL SIDED DEVICE ADJACENT TO FORMER HORN LOCATION. INSTALL DATA IN ADJACENT CEILING SPACE.
16. REFERENCE DIV 27 FOR RACK INFORMATION AND ALLOWANCE REQUIREMENTS. FINAL LOCATIONS TO BE COORDINATED WITH OWNER PRIOR TO INSTALLATION.
17. NOT USED.
18. RECENTLY INSTALLED SPEAKER, REMOVE, PROTECT, AND REDEPLOY WHERE OTHER NEW ANALOG CEILING SPEAKERS ARE NEEDED.
19. J-BOX LARGER THAN 4X4" NEEDED HERE. PROVIDE ADDITIONAL SLACK FOR FUTURE RETERMINATIONS.
20. FIELD CONDITIONS MAY DIFFER FROM WHAT IS SHOWN. COORDINATE EXACT LOCATION WITH OWNER.
21. GYP CEILING. CONTRACTOR SHALL ACCOUNT FOR THREE (3) 24"x24" ACCESS PANEL LOCATIONS IN PRICING. VERIFY PATHWAYS ON SITE.

Description

Date

Revision

Project

SAN ANGELO ISD
PAGING UPGRADE
SAN ANGELO, TEXAS
D-SAN-1003-01




CRUX
TECHNOLOGY • SECURITY SOLUTIONS
800.665.6440
www.cruxsolutions.com

FLOOR PLAN - CENTRAL
HS - BUILDING H - TENNIS

Job No.
D-SAN-1003-01
Drawn By:
CV
Designed By:
CV
Date:
04/29/2026

Sheet No.
T109

Autodesk Docs\CRUX-San Angelo ISD Paging System Upgrade\B SAN-1003-01 SANSD HS_Paging Upgrade_Tech_02\HOSTED.rvt

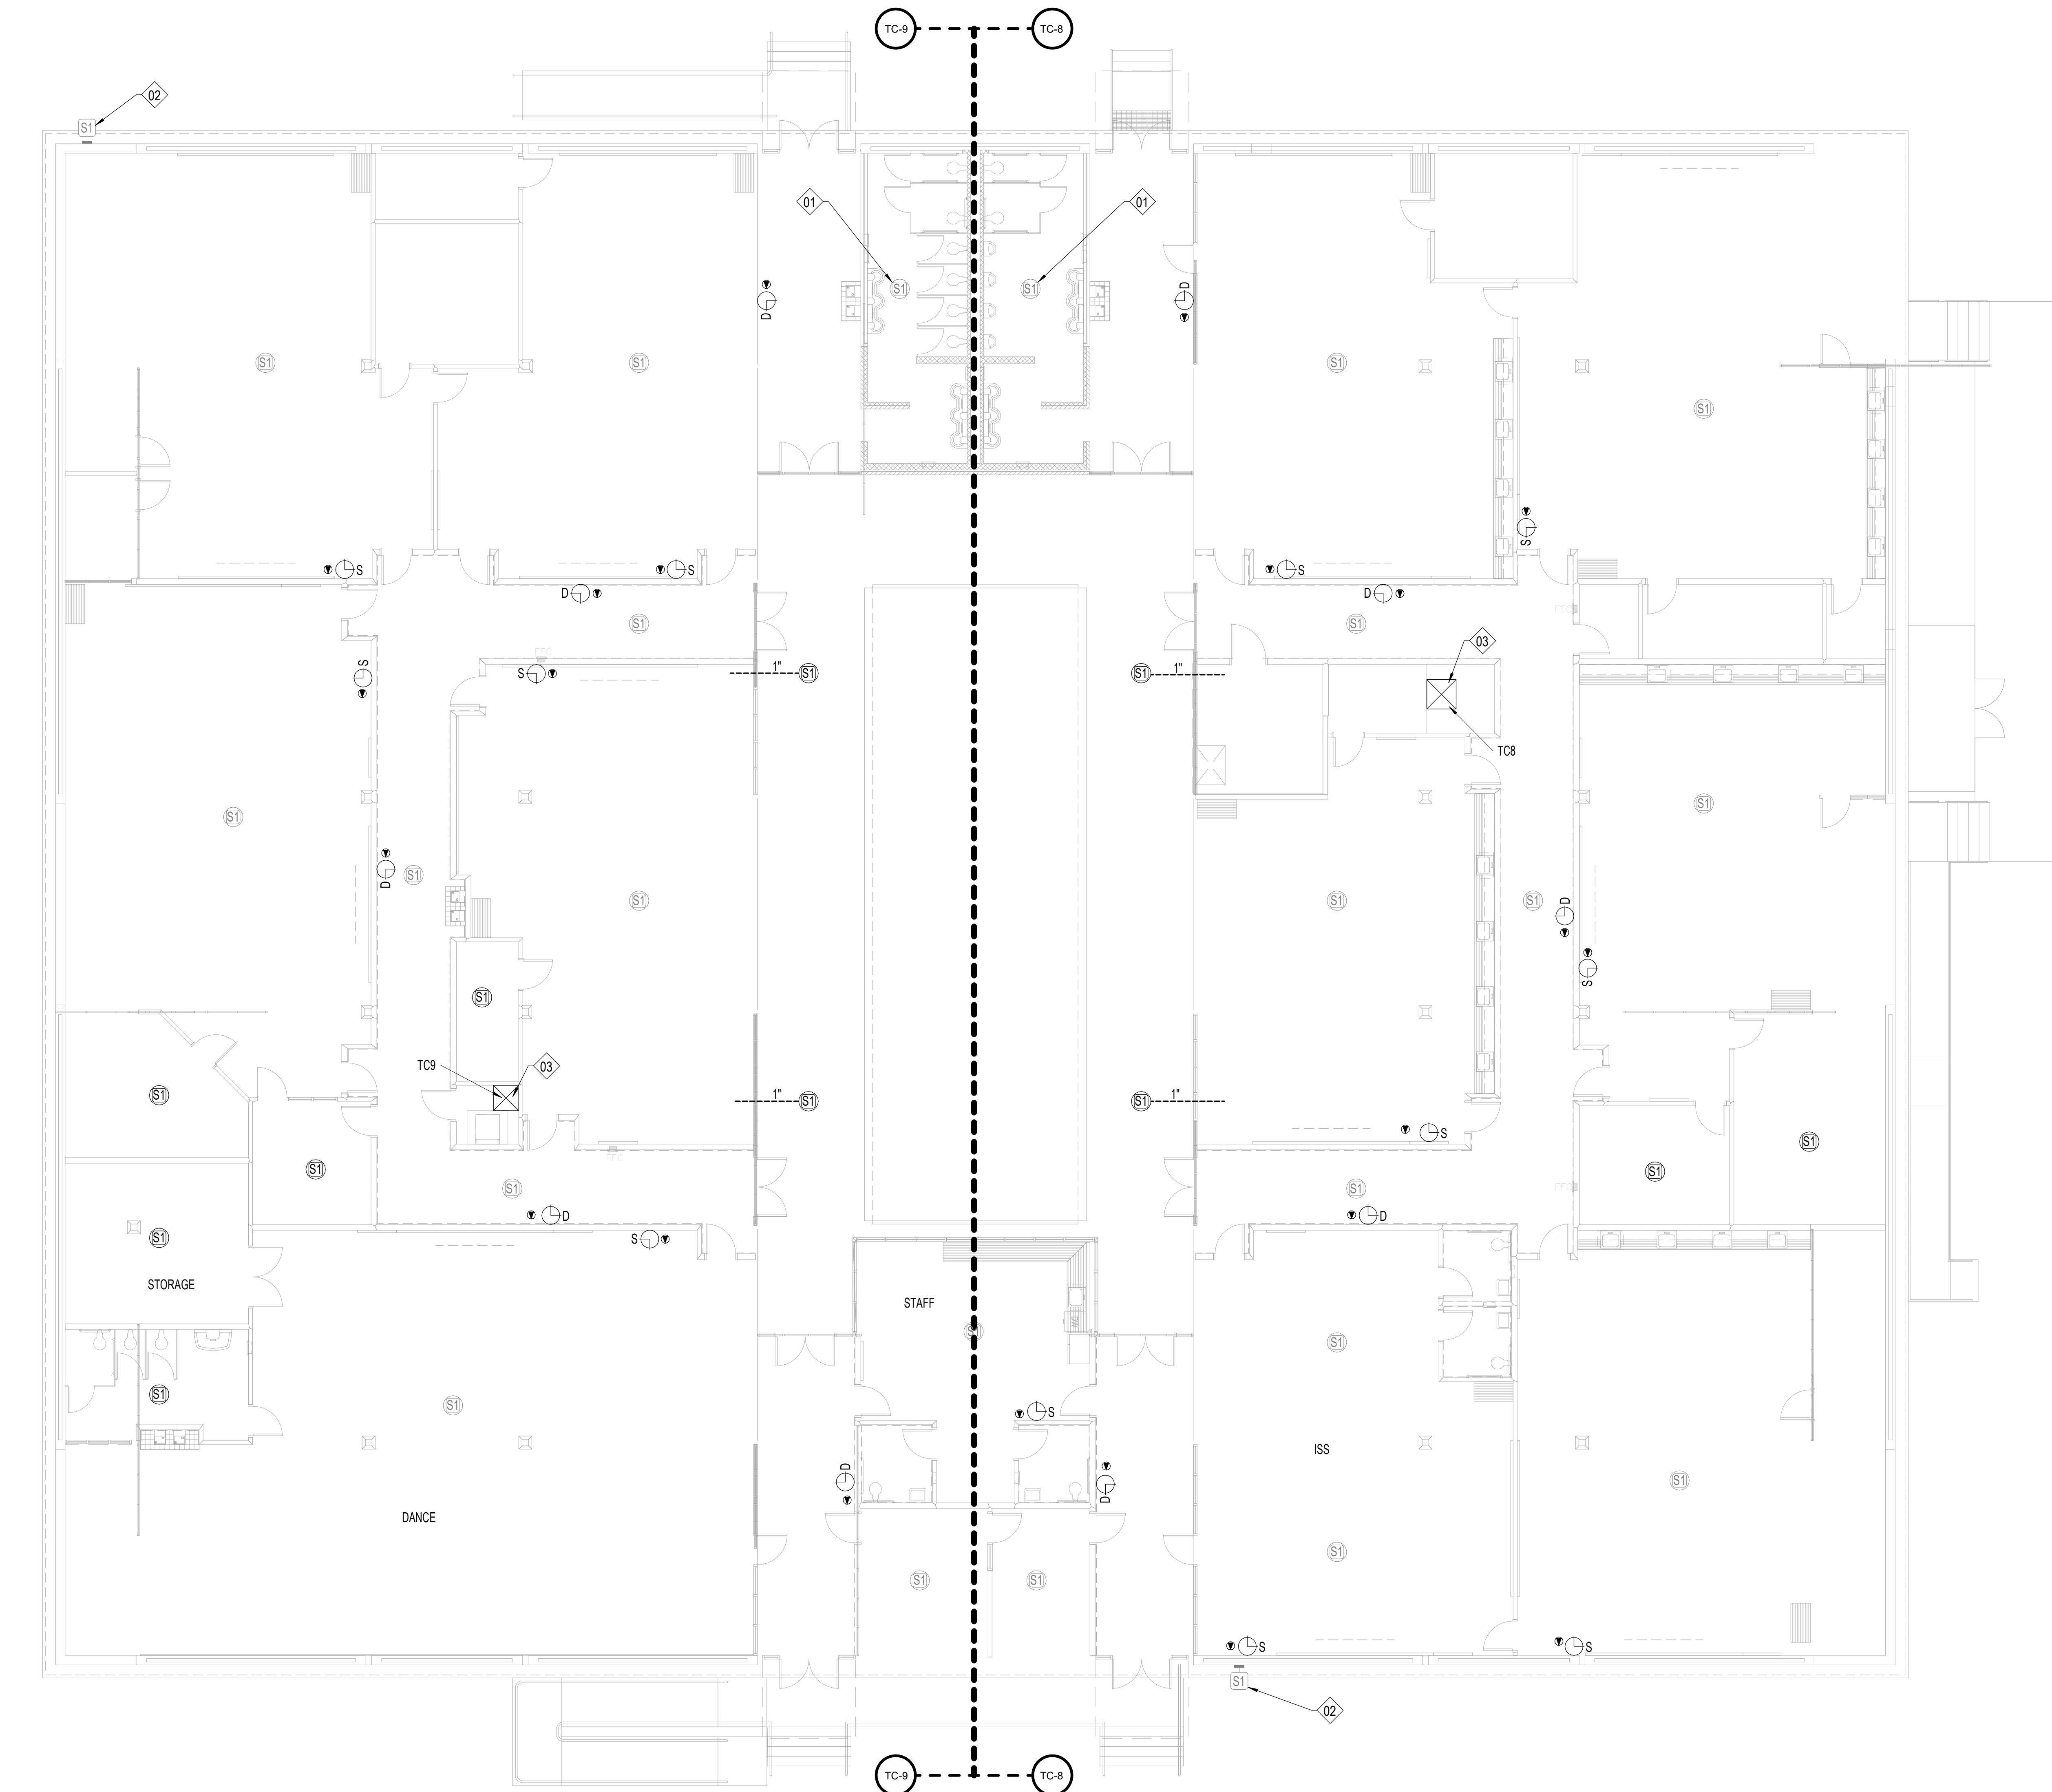

1 FLOOR PLAN - CENTRAL HS - BUILDING I - SCHWEITZER
T110 1/8" = 1'-0"

SHEET NOTES:

REFERENCE SHEET TG101 FOR ALL SYMBOLS AND PROJECT SPECIFIC NOTES.

EXISTING PAGING SPEAKERS (S1) ARE SHOWN IN HALF-TONE. CONTRACTOR SHALL REMOVE EXISTING PAGING SPEAKERS (S1) AND REPLACE WITH CEILING TILE OR BLANK COVER PLATE, UNO.

ALL CONDUITS SHALL BE 1" FOR ALL DEVICES UNLESS NOTED OTHERWISE ON THE TECHNOLOGY DRAWINGS.

IN AREAS WITH CONCRETE OR MASONRY WALLS, CONTRACTOR SHALL PROVIDE SURFACE RACEWAY SYSTEM.

IN AREAS WITH EXPOSED CEILINGS, CONTRACTOR SHALL INSTALL ALL CABLING IN CONDUIT. CONTRACTOR TO PERFORM PAINT FINISH AS COORDINATED WITH OWNER.

CONTRACTOR SHALL DEMOLISH ANY UNUSED CABLING BACK TO ITS ORIGIN AND DISPOSE.

CONTRACTOR SHALL REPLACE ALL EXISTING PTT BUTTONS PRESENT IN THE FACILITY WITH A BLANK COVER PLATE. CONTRACTOR SHALL LOCATE, DOCUMENT AND REMEDIATE IN THE SAME METHOD ANY PTT BUTTON NOT EXPLICITLY SHOWN IN THIS DRAWING SET.

CONTRACTOR IS RESPONSIBLE FOR PROVIDING LIFT FOR ALL HIGH CEILING AREAS (FINE ARTS, GYM, ETC.). CONTRACTOR SHALL ALSO BE REQUIRED TO PROVIDE FLOORING PROTECTION.

KEYNOTE LEGEND

(NOT ALL KEYNOTES MAY APPLY.)

01. EXISTING, CONTRACTOR SHALL REPLACE WITH NEW DEVICE AND NEW CABLING. CEILING TILE MAY REMAIN IN PLACE UNLESS DAMAGED.

02. EXISTING, TO REMAIN. CONTRACTOR SHALL INSTALL BRIDGE FROM ANALOG SPEAKER TO IP HEAD END.

03. CONTRACTOR SHALL COMPLETELY REMOVE ALL ABANDONED ANALOG SPEAKER WIRING AND SUPPORTING TERMINAL BLOCKS FROM THE FACILITY. TERMINAL BLOCKS THAT SUPPORT OTHER EXISTING DEVICES SHALL REMAIN.

04. INSTALL PLASTIC 1/2" RACEWAY FOR PATCH CABLE TO TOP OF SURFACE MOUNTED CLOCK BACK BOX. TERMINATE DATA ABOVE CEILING.

05. EXISTING, CONTRACTOR SHALL REMOVE DEVICE, DEMOLISH CABLING BACK TO ITS ORIGIN, AND INSTALL NEW BLANK FACEPLATE.

06. INSTALL DATA IN ADJACENT OVERHEAD CEILING SPACE. PROVIDE 1" SLEEVE THROUGH CMU WALL TO BACK OF CLOCK DISPLAY.

07. SURFACE MOUNTED CONDUIT NEEDED FOR ALL NEW PAGING AND RELATED DEVICES.

08. PROVIDE 1" CONDUIT TO TOP OF SURFACE MOUNTED CLOCK BACK BOX FOR PATCH CABLE. DATA SHALL BE TERMINATED ABOVE CEILING.

09. INSTALL SURFACE MOUNTED RACEWAY FROM DEVICE BACK TO TECH CLOSET LOCATION.

10. CEILING SPEAKER IN CAN MOUNTED TO STRUCTURAL STEEL.

11. THIS IS A PLASTER CEILING, CONDUIT OR PLASTIC RACEWAY WILL NEED TO BE SECURED TO THE CEILING ITSELF.

12. SPEAKERS MOUNTED TO STRUCTURAL STEEL.

13. INSTALL SURFACE RACEWAY FOR ENTIRE PATH FROM TC TO DEVICE.

14. EXISTING SPEAKER BUILT FLUSH IN WALL. DO NOT REMOVE. INSTALL NEW DEVICE ADJACENT TO EXISTING. INSTALL DATA DROP IN ACCESSIBLE CEILING IN ADJACENT SPACE.

15. REMOVE EXISTING HORNS AND LEAVE MOUNTS INTACT. REMOVE EXISTING CABLING. INSTALL NEW DUAL SIDED DEVICE ADJACENT TO FORMER HORN LOCATION. INSTALL DATA IN ADJACENT CEILING SPACE.

16. REFERENCE DIV 27 FOR RACK INFORMATION AND ALLOWANCE REQUIREMENTS. FINAL LOCATIONS TO BE COORDINATED WITH OWNER PRIOR TO INSTALLATION.

17. NOT USED.

18. RECENTLY INSTALLED SPEAKER. REMOVE, PROTECT, AND REDEPLOY WHERE OTHER NEW ANALOG CEILING SPEAKERS ARE NEEDED.

19. J-BOX LARGER THAN 4X4" NEEDED HERE. PROVIDE ADDITIONAL SLACK FOR FUTURE RETERMINATIONS.

20. FIELD CONDITIONS MAY DIFFER FROM WHAT IS SHOWN. COORDINATE EXACT LOCATION WITH OWNER.

21. GYP CEILING. CONTRACTOR SHALL ACCOUNT FOR THREE (3) 24"x24" ACCESS PANEL LOCATIONS IN PRICING. VERIFY PATHWAYS ON SITE.

Description

Date

Revision

Project

SAN ANGELO ISD
PAGING UPGRADE
SAN ANGELO, TEXAS
D-SAN-1003-01



CRUX
TECHNOLOGY • SECURITY SOLUTIONS
800.665.6440
www.cruxsolutions.com

FLOOR PLAN - CENTRAL
HS - BUILDING I -
SCHWEITZER

Job No.
D-SAN-1003-01
Drawn By:
CV
Designed By:
CV
Date:
04/29/2026

Sheet No.

T110

21. GYP CEILING. CONTRACTOR SHALL ACCOUNT FOR THREE (3) 24"X24" ACCESS PANEL LOCATIONS IN PRICING. VERIFY PATHWAYS ON SITE.

T111

Autodesk Docs\CRUX-San Angelo ISD Paging System Upgrade\B-SAN-1003-01 SANSD HS_Paging Upgrade_Tech_02(HOSTED).rvt



1 FLOOR PLAN - BACON
T112 1/8" = 1'-0"

SHEET NOTES:

REFERENCE SHEET TG101 FOR ALL SYMBOLS AND PROJECT SPECIFIC NOTES.

EXISTING PAGING SPEAKERS (S1) ARE SHOWN IN HALF-TONE. CONTRACTOR SHALL REMOVE EXISTING PAGING SPEAKERS (S1) AND REPLACE WITH CEILING TILE OR BLANK COVER PLATE, UNLESS NOTED OTHERWISE.

ALL CONDUITS SHALL BE 1" FOR ALL DEVICES UNLESS NOTED OTHERWISE ON THE TECHNOLOGY DRAWINGS.

IN AREAS WITH CONCRETE OR MASONRY WALLS, CONTRACTOR SHALL PROVIDE SURFACE RACEWAY SYSTEM.

IN AREAS WITH EXPOSED CEILINGS, CONTRACTOR SHALL INSTALL ALL CABLING IN CONDUIT. CONTRACTOR TO PERFORM PAINT FINISH AS COORDINATED WITH OWNER.

CONTRACTOR SHALL DEMOLISH ANY UNUSED CABLING BACK TO ITS ORIGIN AND DISPOSE.

CONTRACTOR SHALL REPLACE ALL EXISTING PTT BUTTONS PRESENT IN THE FACILITY WITH A BLANK COVER PLATE. CONTRACTOR SHALL LOCATE, DOCUMENT AND REMEDIATE IN THE SAME METHOD ANY PTT BUTTON NOT EXPLICITLY SHOWN IN THIS DRAWING SET.

CONTRACTOR IS RESPONSIBLE FOR PROVIDING LIFT FOR ALL HIGH CEILING AREAS (FINE ARTS, GYM, ETC.). CONTRACTOR SHALL ALSO BE REQUIRED TO PROVIDE FLOORING PROTECTION.

KEYNOTE LEGEND

(NOT ALL KEYNOTES MAY APPLY.)

01. EXISTING, CONTRACTOR SHALL REPLACE WITH NEW DEVICE AND NEW CABLING. CEILING TILE MAY REMAIN IN PLACE UNLESS DAMAGED.

02. EXISTING, TO REMAIN. CONTRACTOR SHALL INSTALL BRIDGE FROM ANALOG SPEAKER TO IP HEAD END.

03. CONTRACTOR SHALL COMPLETELY REMOVE ALL ABANDONED ANALOG SPEAKER WIRING AND SUPPORTING TERMINAL BLOCKS FROM THE FACILITY. TERMINAL BLOCKS THAT SUPPORT OTHER EXISTING DEVICES SHALL REMAIN.

04. INSTALL PLASTIC 1/2" RACEWAY FOR PATCH CABLE TO TOP OF SURFACE MOUNTED CLOCK BACK BOX. TERMINATE DATA ABOVE CEILING.

05. EXISTING, CONTRACTOR SHALL REMOVE DEVICE, DEMOLISH CABLING BACK TO ITS ORIGIN, AND INSTALL NEW BLANK FACEPLATE.

06. INSTALL DATA IN ADJACENT OVERHEAD CEILING SPACE. PROVIDE 1" SLEEVE THROUGH CMU WALL TO BACK OF CLOCK DISPLAY.

07. SURFACE MOUNTED CONDUIT NEEDED FOR ALL NEW PAGING AND RELATED DEVICES.

08. PROVIDE 1" CONDUIT TO TOP OF SURFACE MOUNTED CLOCK BACK BOX FOR PATCH CABLE. DATA SHALL BE TERMINATED ABOVE CEILING.

09. INSTALL SURFACE MOUNTED RACEWAY FROM DEVICE BACK TO TECH CLOSET LOCATION.

10. CEILING SPEAKER IN CAN MOUNTED TO STRUCTURAL STEEL.

11. THIS IS A PLASTER CEILING, CONDUIT OR PLASTIC RACEWAY WILL NEED TO BE SECURED TO THE CEILING ITSELF.

12. SPEAKERS MOUNTED TO STRUCTURAL STEEL.

13. INSTALL SURFACE RACEWAY FOR ENTIRE PATH FROM TC TO DEVICE.

14. EXISTING SPEAKER BUILT FLUSH IN WALL. DO NOT REMOVE. INSTALL NEW DEVICE ADJACENT TO EXISTING. INSTALL DATA DROP IN ACCESSIBLE CEILING IN ADJACENT SPACE.

15. REMOVE EXISTING HORNS AND LEAVE MOUNTS INTACT, REMOVE EXISTING CABLING. INSTALL NEW DUAL SIDED DEVICE ADJACENT TO FORMER HORN LOCATION. INSTALL DATA IN ADJACENT CEILING SPACE.

16. REFERENCE DIV 27 FOR RACK INFORMATION AND ALLOWANCE REQUIREMENTS. FINAL LOCATIONS TO BE COORDINATED WITH OWNER PRIOR TO INSTALLATION.

17. NOT USED.

18. RECENTLY INSTALLED SPEAKER, REMOVE, PROTECT, AND REDEPLOY WHERE OTHER NEW ANALOG CEILING SPEAKERS ARE NEEDED.

19. J-BOX LARGER THAN 4X4" NEEDED HERE. PROVIDE ADDITIONAL SLACK FOR FUTURE RETERMINATIONS.

20. FIELD CONDITIONS MAY DIFFER FROM WHAT IS SHOWN. COORDINATE EXACT LOCATION WITH OWNER.

21. GYP CEILING. CONTRACTOR SHALL ACCOUNT FOR THREE (3) 24"x24" ACCESS PANEL LOCATIONS IN PRICING. VERIFY PATHWAYS ON SITE.

Description

Date

Revision

Project

SAN ANGELO ISD
PAGING UPGRADE
SAN ANGELO, TEXAS
D-SAN-1003-01





FLOOR PLAN - CENTRAL
HS - BUILDING K - BACON

Job No.
D-SAN-1003-01
Drawn By:
CV
Designed By:
CV
Date:
04/29/2026

Sheet No.

T112

Autodesk Docs\CRUX-San Angelo ISD Paging System Upgrade\B SAN-1003-01 SANSD HS_Paging Upgrade_Tech_L22(POSTED).rvt

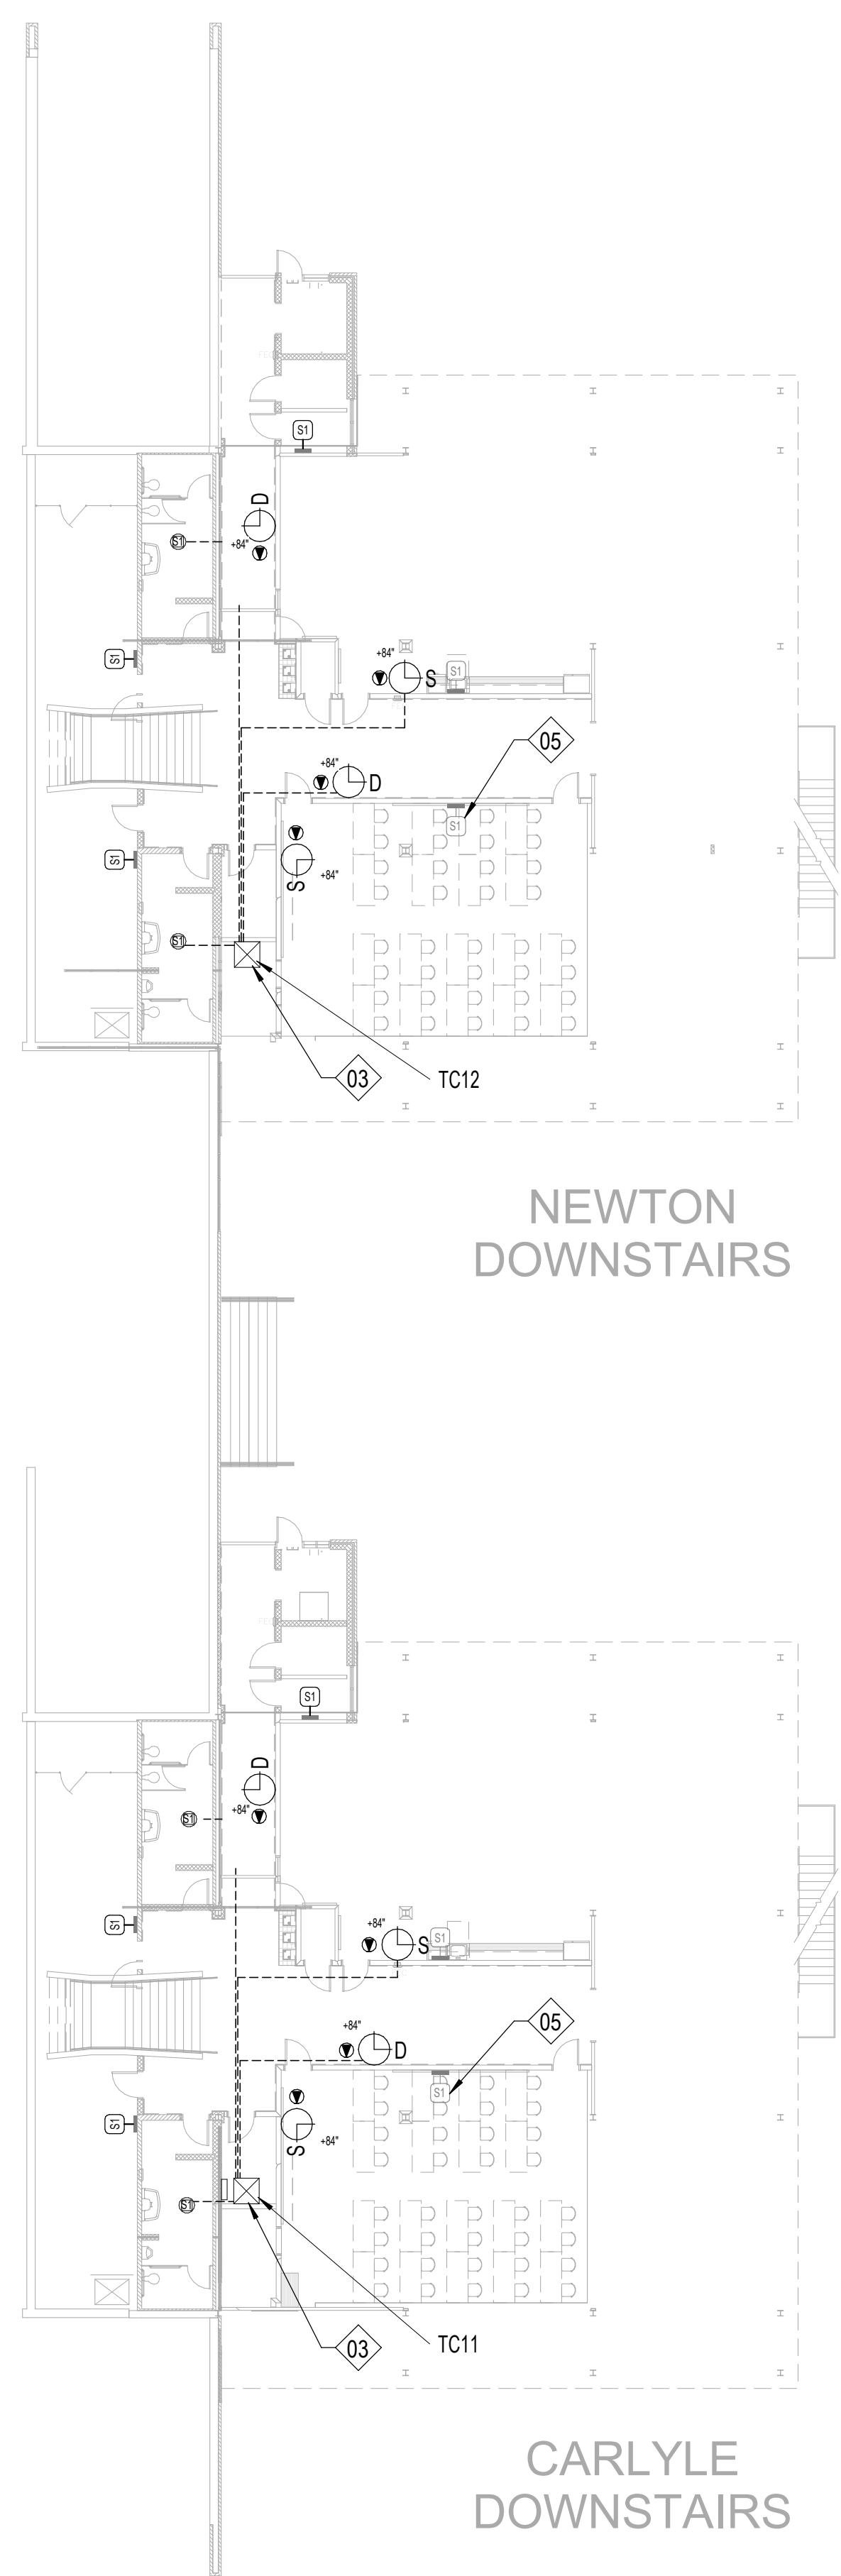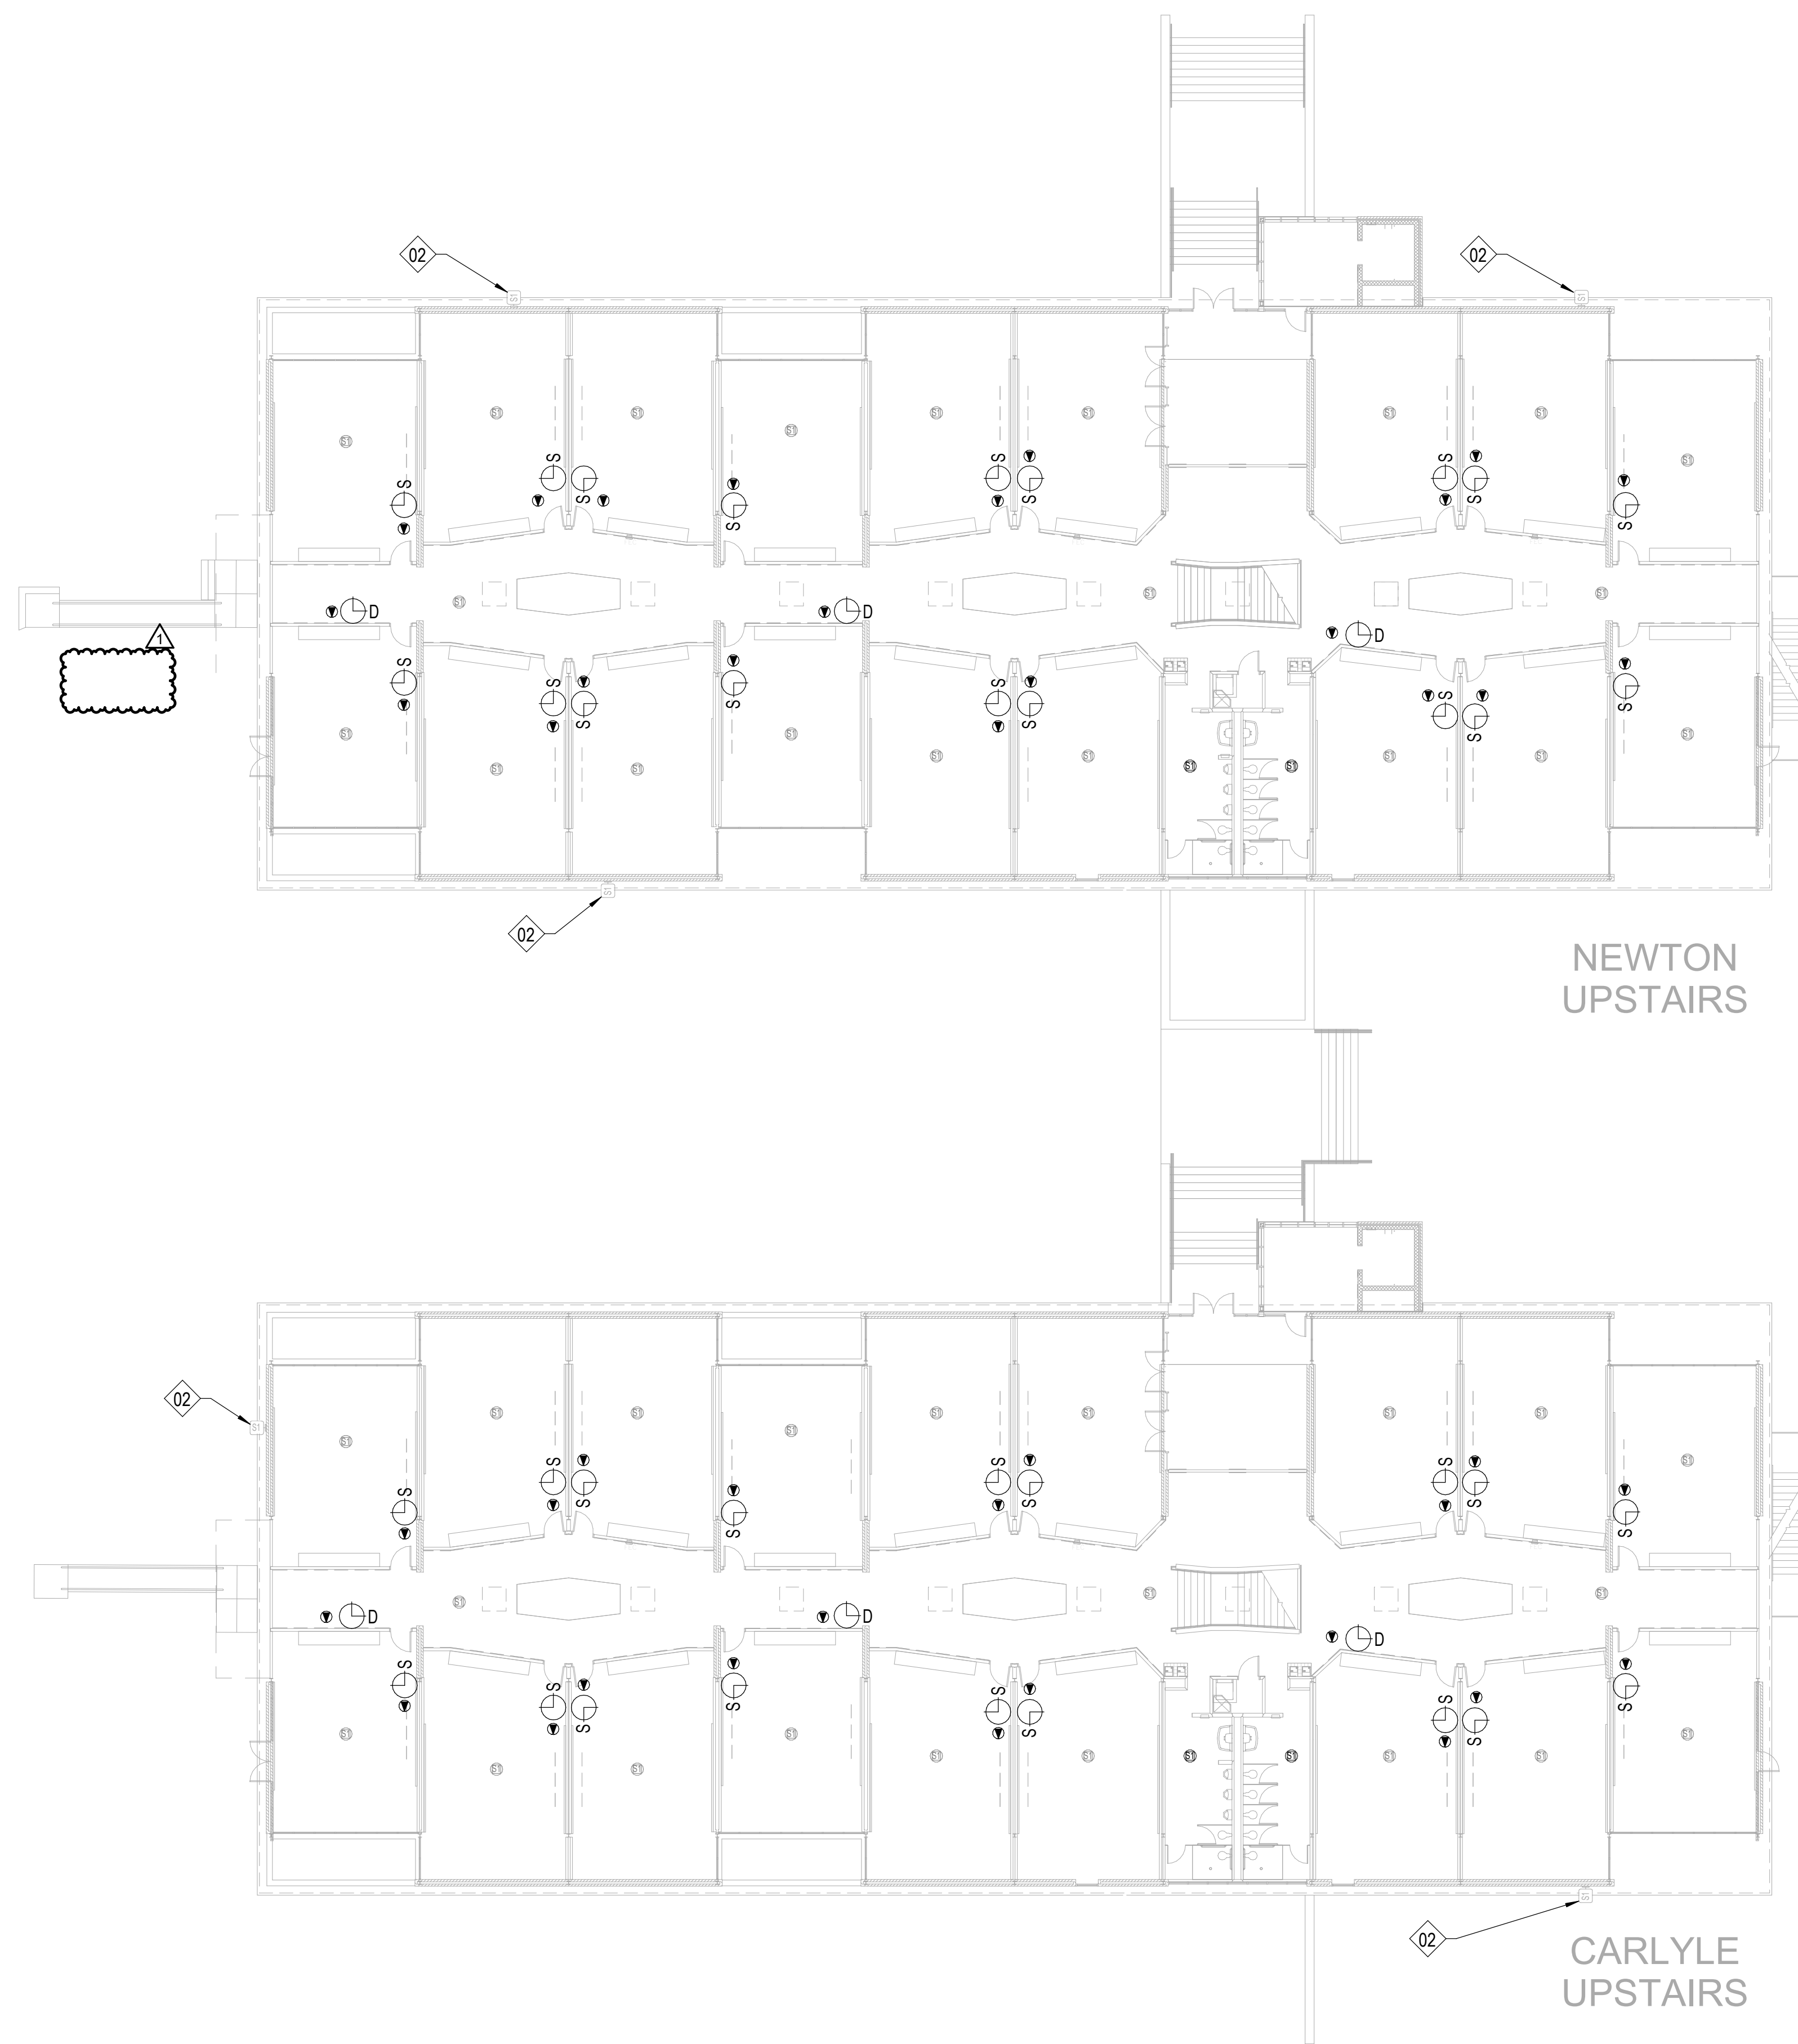

SHEET NOTES:

REFERENCE SHEET TG101 FOR ALL SYMBOLS AND PROJECT SPECIFIC NOTES.

EXISTING PAGING SPEAKERS (S1) ARE SHOWN IN HALF-TONE. CONTRACTOR SHALL REMOVE EXISTING PAGING SPEAKERS (S1) AND REPLACE WITH CEILING TILE OR BLANK COVER PLATE, U.N.O.

ALL CONDUITS SHALL BE 1" FOR ALL DEVICES UNLESS NOTED OTHERWISE ON THE TECHNOLOGY DRAWINGS.

IN AREAS WITH CONCRETE OR MASONRY WALLS, CONTRACTOR SHALL PROVIDE SURFACE RACEWAY SYSTEM.

IN AREAS WITH EXPOSED CEILINGS, CONTRACTOR SHALL INSTALL ALL CABLING IN CONDUIT. CONTRACTOR TO PERFORM PAINT FINISH AS COORDINATED WITH OWNER.

CONTRACTOR SHALL DEMOLISH ANY UNUSED CABLING BACK TO ITS ORIGIN AND DISPOSE.

CONTRACTOR SHALL REPLACE ALL EXISTING PTT BUTTONS PRESENT IN THE FACILITY WITH A BLANK COVER PLATE. CONTRACTOR SHALL LOCATE, DOCUMENT AND REMEDIATE IN THE SAME METHOD ANY PTT BUTTON NOT EXPLICITLY SHOWN IN THIS DRAWING SET.

CONTRACTOR IS RESPONSIBLE FOR PROVIDING LIFT FOR ALL HIGH CEILING AREAS (FINE ARTS, GYM, ETC.). CONTRACTOR SHALL ALSO BE REQUIRED TO PROVIDE FLOORING PROTECTION.

KEYNOTE LEGEND

(NOT ALL KEYNOTES MAY APPLY.)

01. EXISTING, CONTRACTOR SHALL REPLACE WITH NEW DEVICE AND NEW CABLING. CEILING TILE MAY REMAIN IN PLACE UNLESS DAMAGED.
02. EXISTING, TO REMAIN. CONTRACTOR SHALL INSTALL BRIDGE FROM ANALOG SPEAKER TO IP HEAD END.
03. CONTRACTOR SHALL COMPLETELY REMOVE ALL ABANDONED ANALOG SPEAKER WIRING AND SUPPORTING TERMINAL BLOCKS FROM THE FACILITY. TERMINAL BLOCKS THAT SUPPORT OTHER EXISTING DEVICES SHALL REMAIN.
04. INSTALL PLASTIC 1/2" RACEWAY FOR PATCH CABLE TO TOP OF SURFACE MOUNTED CLOCK BACK BOX. TERMINATE DATA ABOVE CEILING.
05. EXISTING, CONTRACTOR SHALL REMOVE DEVICE, DEMOLISH CABLING BACK TO ITS ORIGIN, AND INSTALL NEW BLANK FACEPLATE.
06. INSTALL DATA IN ADJACENT OVERHEAD CEILING SPACE. PROVIDE 1" SLEEVE THROUGH CMU WALL TO BACK OF CLOCK DISPLAY.
07. SURFACE MOUNTED CONDUIT NEEDED FOR ALL NEW PAGING AND RELATED DEVICES.
08. PROVIDE 1" CONDUIT TO TOP OF SURFACE MOUNTED CLOCK BACK BOX FOR PATCH CABLE. DATA SHALL BE TERMINATED ABOVE CEILING.
09. INSTALL SURFACE MOUNTED RACEWAY FROM DEVICE BACK TO TECH CLOSET LOCATION.
10. CEILING SPEAKER IN CAN MOUNTED TO STRUCTURAL STEEL.
11. THIS IS A PLASTER CEILING, CONDUIT OR PLASTIC RACEWAY WILL NEED TO BE SECURED TO THE CEILING ITSELF.
12. SPEAKERS MOUNTED TO STRUCTURAL STEEL.
13. INSTALL SURFACE RACEWAY FOR ENTIRE PATH FROM TC TO DEVICE.
14. EXISTING SPEAKER BUILT FLUSH IN WALL. DO NOT REMOVE. INSTALL NEW DEVICE ADJACENT TO EXISTING. INSTALL DATA DROP IN ACCESSIBLE CEILING IN ADJACENT SPACE.
15. REMOVE EXISTING HORNS AND LEAVE MOUNTS INTACT, REMOVE EXISTING CABLING. INSTALL NEW DUAL SIDED DEVICE ADJACENT TO FORMER HORN LOCATION. INSTALL DATA IN ADJACENT CEILING SPACE.
16. REFERENCE DIV 27 FOR RACK INFORMATION AND ALLOWANCE REQUIREMENTS. FINAL LOCATIONS TO BE COORDINATED WITH OWNER PRIOR TO INSTALLATION.
17. NOT USED.
18. RECENTLY INSTALLED SPEAKER, REMOVE, PROTECT, AND REDEPLOY WHERE OTHER NEW ANALOG CEILING SPEAKERS ARE NEEDED.
19. J-BOX LARGER THAN 4X4" NEEDED HERE. PROVIDE ADDITIONAL SLACK FOR FUTURE RETERMINATIONS.
20. FIELD CONDITIONS MAY DIFFER FROM WHAT IS SHOWN. COORDINATE EXACT LOCATION WITH OWNER.
21. GYP CEILING. CONTRACTOR SHALL ACCOUNT FOR THREE (3) 24"X24" ACCESS PANEL LOCATIONS IN PRICING. VERIFY PATHWAYS ON SITE.

1 FLOOR PLAN - CENTRAL HS - BUILDINGS L & M - CARLYLE & NEWTON
T113 1/16" = 1'-0"

Description

Addendum 01

Date: 05/18/25

Revision: 1

SAN ANGELO ISD
PAGING UPGRADE
SAN ANGELO, TEXAS
D-SAN-1003-01

Project:



CRUX
TECHNOLOGY • SECURITY SOLUTIONS
800.665.6440
www.cruxsolutions.com

FLOOR PLAN - CENTRAL
HS - BUILDING M & L -
CARLYLE & NEWTON

Job No.

D-SAN-1003-01

Drawn By:

CV

Designed By:

CV


Date:

04/29/2025

Sheet No.

T113

Autodesk Docs\CRUX-San Angelo ISD Paging System Upgrade\B SAN-1003-01 SANSD HS_Paging Upgrade_Tech_02(HOSTED).rvt

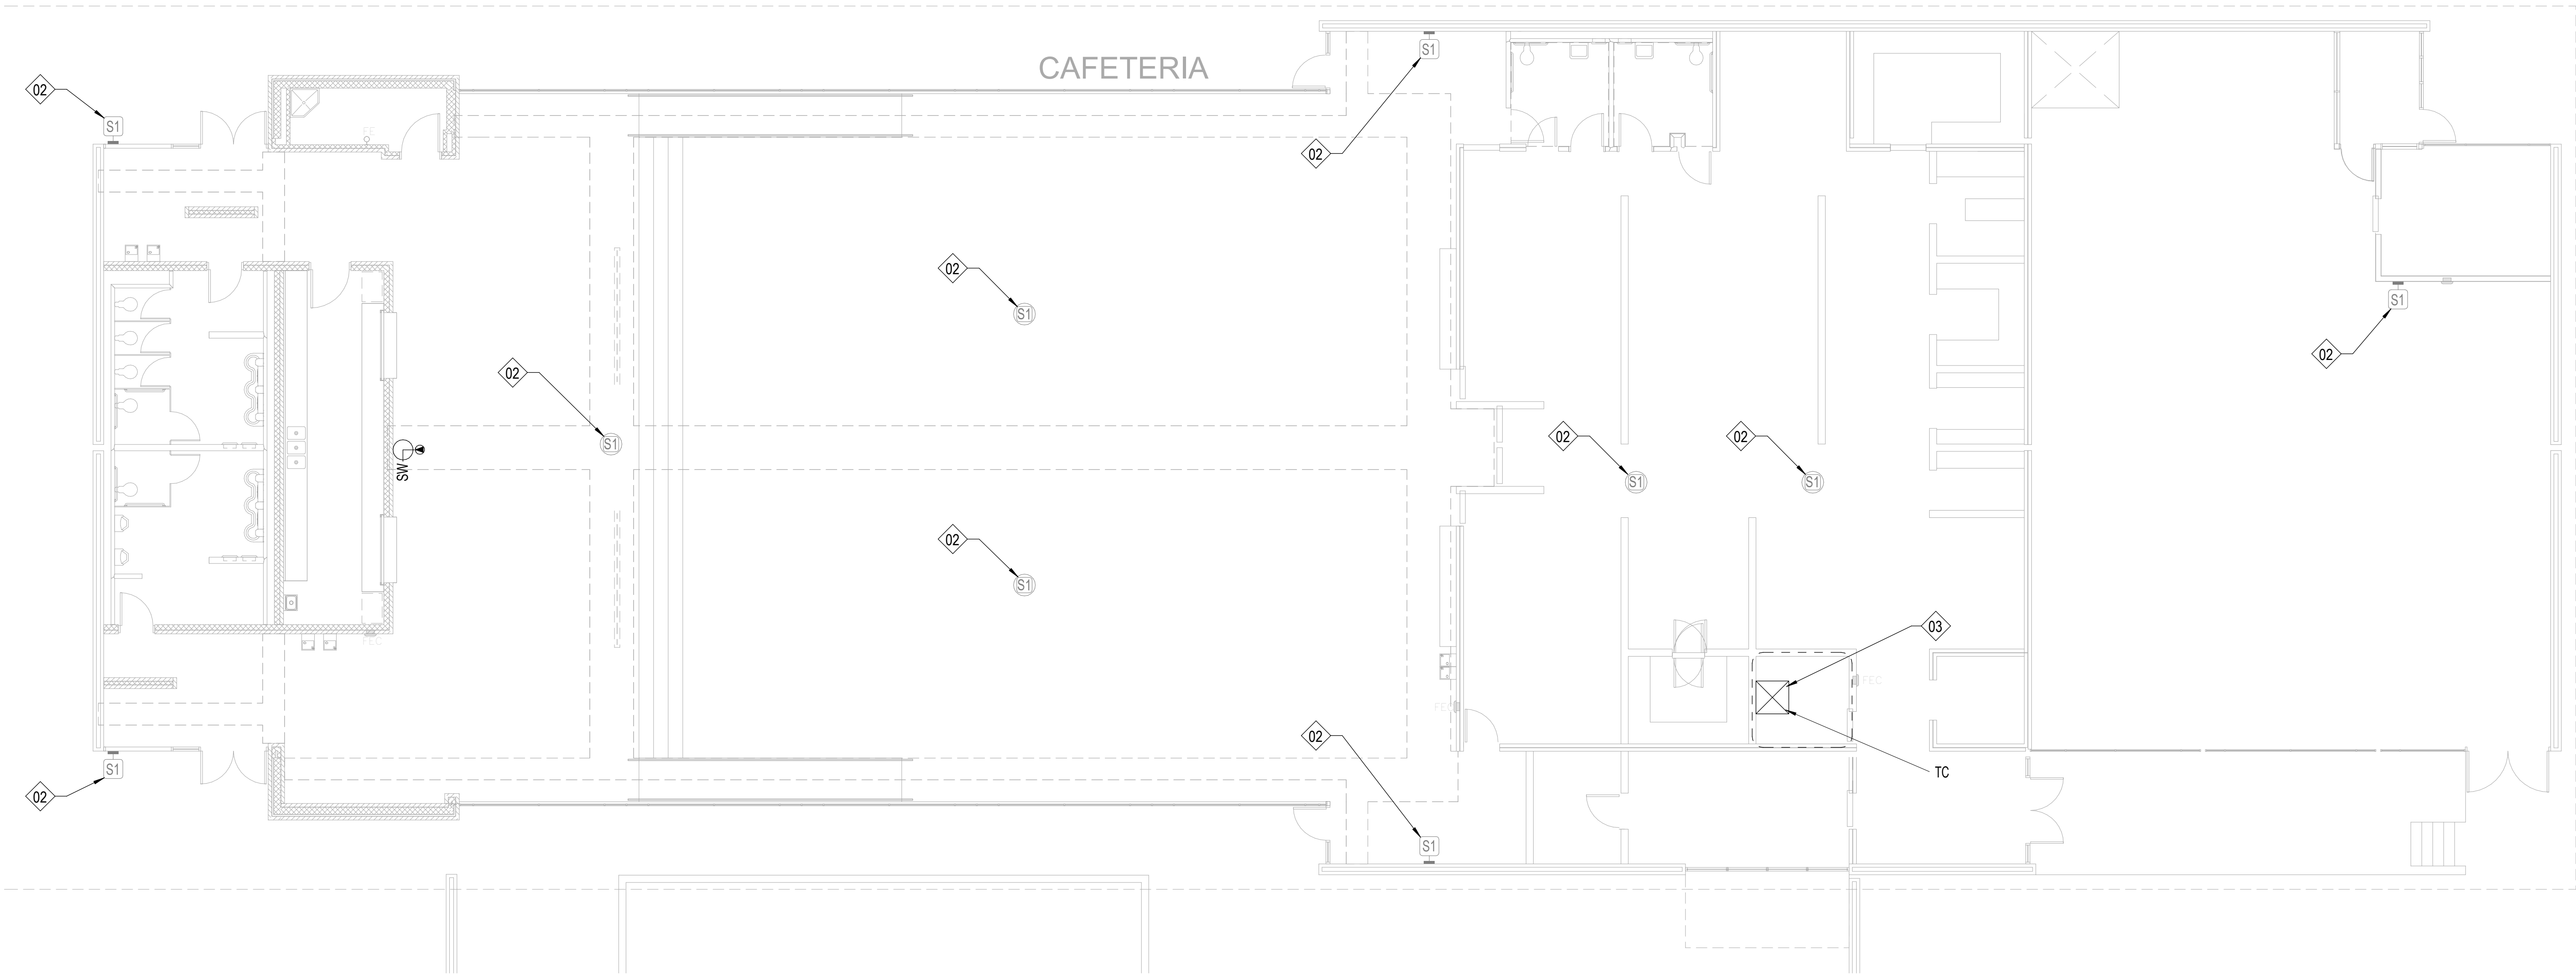

1 FLOOR PLAN - CENTRAL HS - BUILDING N - TWAIN
1/8" = 1'-0"

SHEET NOTES:

- REFERENCE SHEET TG101 FOR ALL SYMBOLS AND PROJECT SPECIFIC NOTES.
- EXISTING PAGING SPEAKERS (S1) ARE SHOWN IN HALF-TONE. CONTRACTOR SHALL REMOVE EXISTING PAGING SPEAKERS (S1) AND REPLACE WITH CEILING TILE OR BLANK COVER PLATE, UNO.
- ALL CONDUITS SHALL BE 1" FOR ALL DEVICES UNLESS NOTED OTHERWISE ON THE TECHNOLOGY DRAWINGS.
- IN AREAS WITH CONCRETE OR MASONRY WALLS, CONTRACTOR SHALL PROVIDE SURFACE RACEWAY SYSTEM.
- IN AREAS WITH EXPOSED CEILINGS, CONTRACTOR SHALL INSTALL ALL CABLING IN CONDUIT. CONTRACTOR TO PERFORM PAINT FINISH AS COORDINATED WITH OWNER.
- CONTRACTOR SHALL DEMOLISH ANY UNUSED CABLING BACK TO ITS ORIGIN AND DISPOSE.
- CONTRACTOR SHALL REPLACE ALL EXISTING PTT BUTTONS PRESENT IN THE FACILITY WITH A BLANK COVER PLATE. CONTRACTOR SHALL LOCATE, DOCUMENT AND REMEDIATE IN THE SAME METHOD ANY PTT BUTTON NOT EXPLICITLY SHOWN IN THIS DRAWING SET.
- CONTRACTOR IS RESPONSIBLE FOR PROVIDING LIFT FOR ALL HIGH CEILING AREAS (FINE ARTS, GYM, ETC.). CONTRACTOR SHALL ALSO BE REQUIRED TO PROVIDE FLOORING PROTECTION.

KEYNOTE LEGEND

- (NOT ALL KEYNOTES MAY APPLY.)
01. EXISTING, CONTRACTOR SHALL REPLACE WITH NEW DEVICE AND NEW CABLING. CEILING TILE MAY REMAIN IN PLACE UNLESS DAMAGED.
02. EXISTING, TO REMAIN. CONTRACTOR SHALL INSTALL BRIDGE FROM ANALOG SPEAKER TO IP HEAD END.
03. CONTRACTOR SHALL COMPLETELY REMOVE ALL ABANDONED ANALOG SPEAKER WIRING AND SUPPORTING TERMINAL BLOCKS FROM THE FACILITY. TERMINAL BLOCKS THAT SUPPORT OTHER EXISTING DEVICES SHALL REMAIN.
04. INSTALL PLASTIC 1/2" RACEWAY FOR PATCH CABLE TO TOP OF SURFACE MOUNTED CLOCK BACK BOX. TERMINATE DATA ABOVE CEILING.
05. EXISTING, CONTRACTOR SHALL REMOVE DEVICE, DEMOLISH CABLING BACK TO ITS ORIGIN, AND INSTALL NEW BLANK FACEPLATE.
06. INSTALL DATA IN ADJACENT OVERHEAD CEILING SPACE. PROVIDE 1" SLEEVE THROUGH CMU WALL TO BACK OF CLOCK DISPLAY.
07. SURFACE MOUNTED CONDUIT NEEDED FOR ALL NEW PAGING AND RELATED DEVICES.
08. PROVIDE 1" CONDUIT TO TOP OF SURFACE MOUNTED CLOCK BACK BOX FOR PATCH CABLE. DATA SHALL BE TERMINATED ABOVE CEILING.
09. INSTALL SURFACE MOUNTED RACEWAY FROM DEVICE BACK TO TECH CLOSET LOCATION.
10. CEILING SPEAKER IN CAN MOUNTED TO STRUCTURAL STEEL.
11. THIS IS A PLASTER CEILING, CONDUIT OR PLASTIC RACEWAY WILL NEED TO BE SECURED TO THE CEILING ITSELF.
12. SPEAKERS MOUNTED TO STRUCTURAL STEEL.
13. INSTALL SURFACE RACEWAY FOR ENTIRE PATH FROM TC TO DEVICE.
14. EXISTING SPEAKER BUILT FLUSH IN WALL. DO NOT REMOVE. INSTALL NEW DEVICE ADJACENT TO EXISTING. INSTALL DATA DROP IN ACCESSIBLE CEILING IN ADJACENT SPACE.
15. REMOVE EXISTING HORNS AND LEAVE MOUNTS INTACT, REMOVE EXISTING CABLING. INSTALL NEW DUAL SIDED DEVICE ADJACENT TO FORMER HORN LOCATION. INSTALL DATA IN ADJACENT CEILING SPACE.
16. REFERENCE DIV 27 FOR RACK INFORMATION AND ALLOWANCE REQUIREMENTS. FINAL LOCATIONS TO BE COORDINATED WITH OWNER PRIOR TO INSTALLATION.
17. NOT USED.
18. RECENTLY INSTALLED SPEAKER, REMOVE, PROTECT, AND REDEPLOY WHERE OTHER NEW ANALOG CEILING SPEAKERS ARE NEEDED.
19. J-BOX LARGER THAN 4X4" NEEDED HERE. PROVIDE ADDITIONAL SLACK FOR FUTURE RETERMINATIONS.
20. FIELD CONDITIONS MAY DIFFER FROM WHAT IS SHOWN. COORDINATE EXACT LOCATION WITH OWNER.
21. GYP CEILING. CONTRACTOR SHALL ACCOUNT FOR THREE (3) 24"X24" ACCESS PANEL LOCATIONS IN PRICING. VERIFY PATHWAYS ON SITE.

Description

Date

Revision

Project


SAN ANGELO ISD
PAGING UPGRADE
SAN ANGELO, TEXAS
D-SAN-1003-01



FLOOR PLAN - CENTRAL
HS - BUILDING N - TWAIN


Job No. D-SAN-1003-01	Sheet No.
Drawn By: CV	T114
Designed By: CV	
Date: 04/29/2026	

Autodesk Docs\CRUX-San Angelo ISD Paging System Upgrade\B SAN-1003-01 SANSD HS_Paging Upgrade_Tech_02(HOSTED).rvt

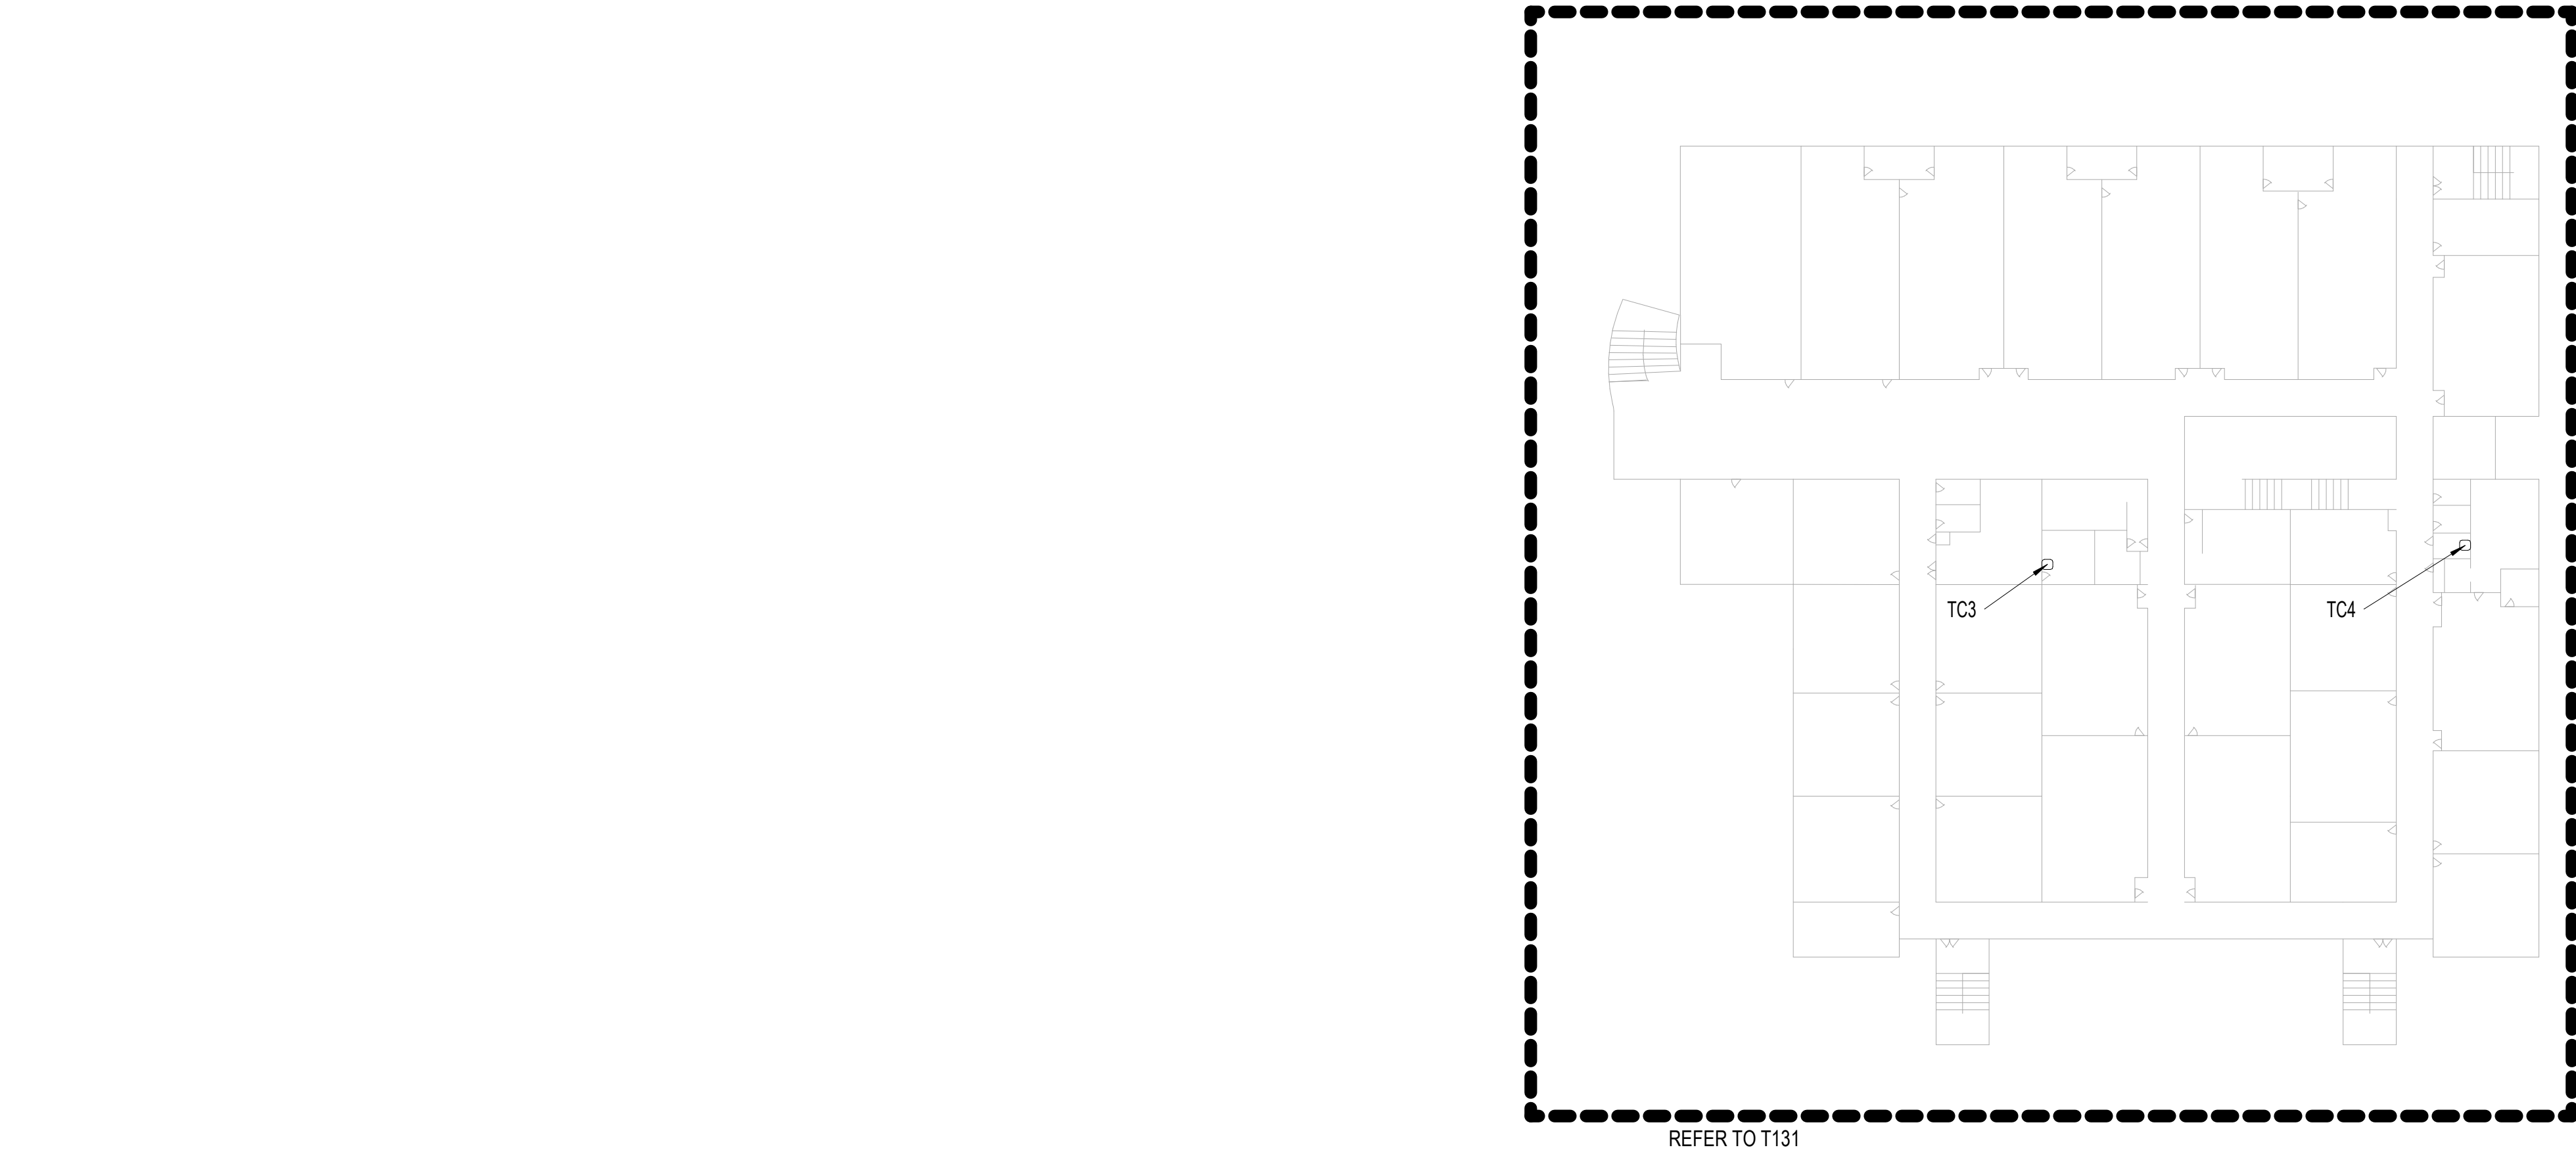


2 OVERALL FLOOR PLAN - LAKE VIEW HS - SECOND FLOOR
T115 1" = 50'-0"


BUILDINGS C - REFER TO T132

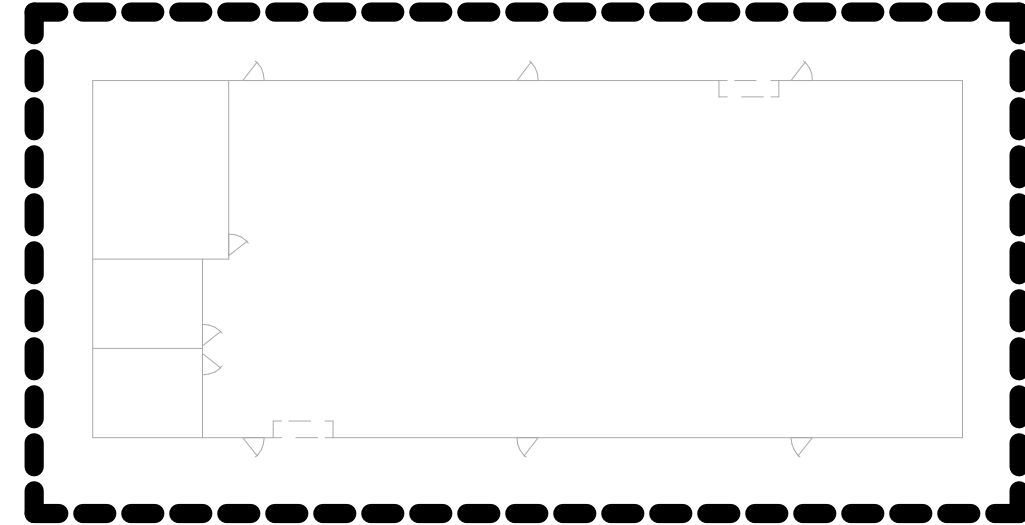


PORTABLE (SNACK SHACK) - REFER TO T135

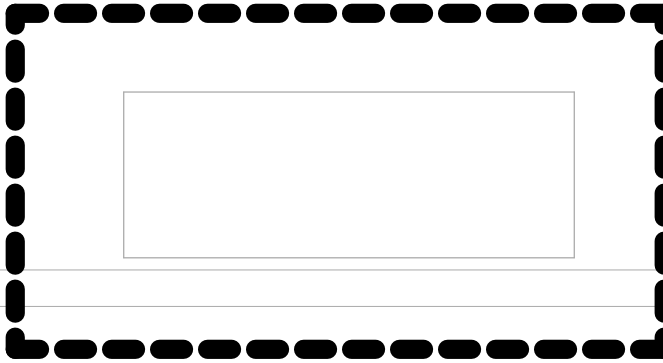


BUILDING D - REFER TO T133

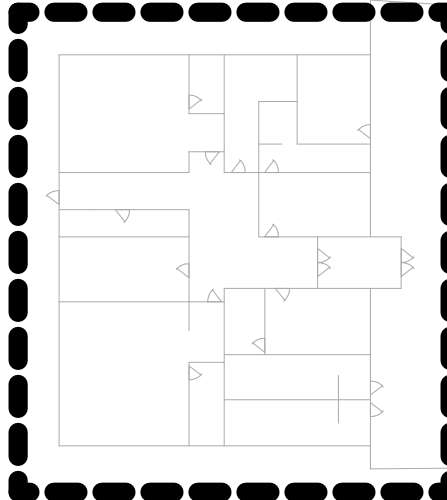



BUILDING E (ROT) - NOT IN SCOPE

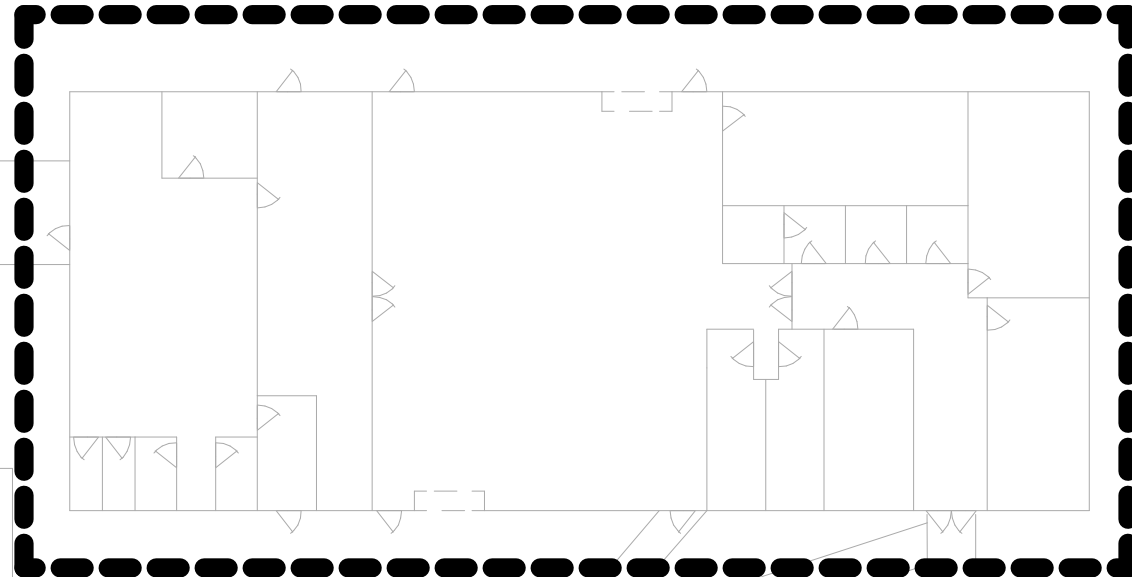


BUILDING F - NOT IN SCOPE

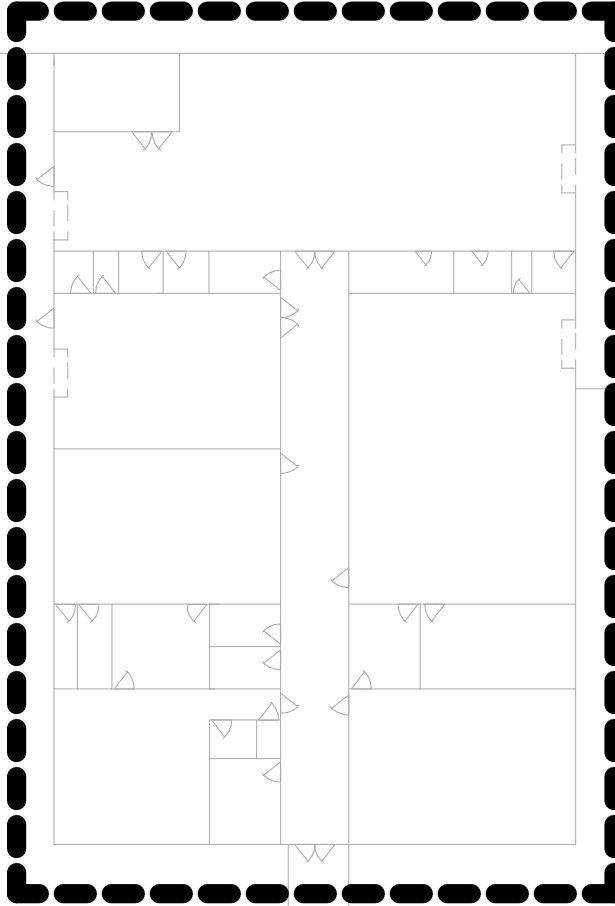

BUILDING G - REFER TO T134

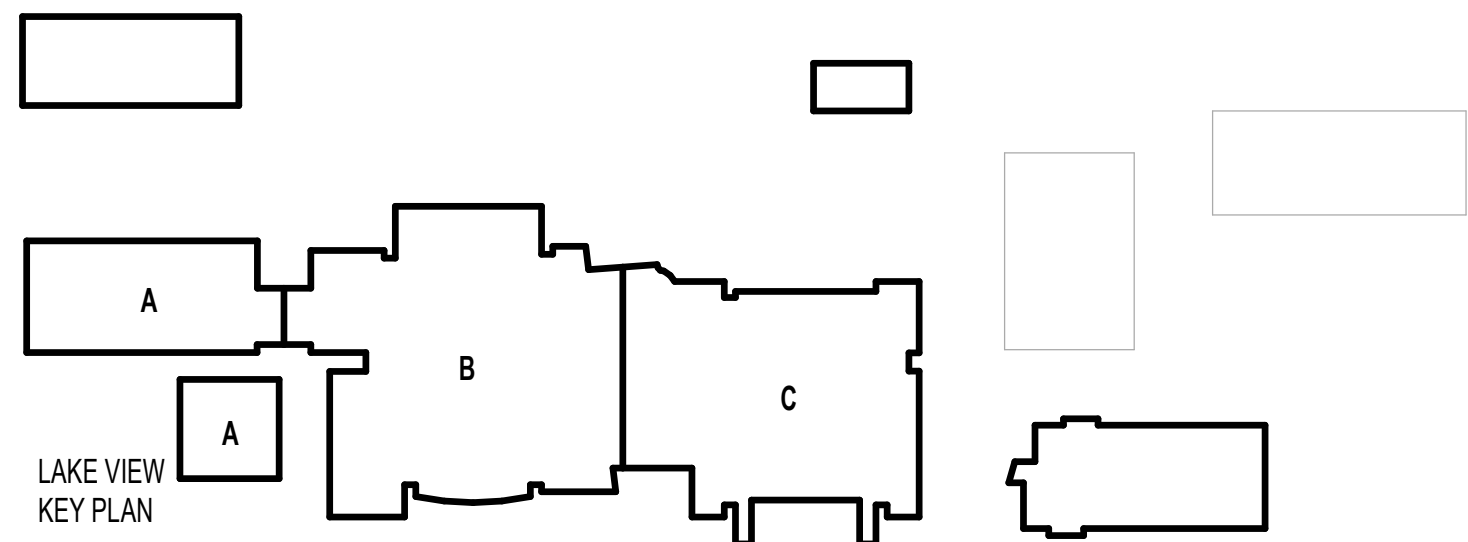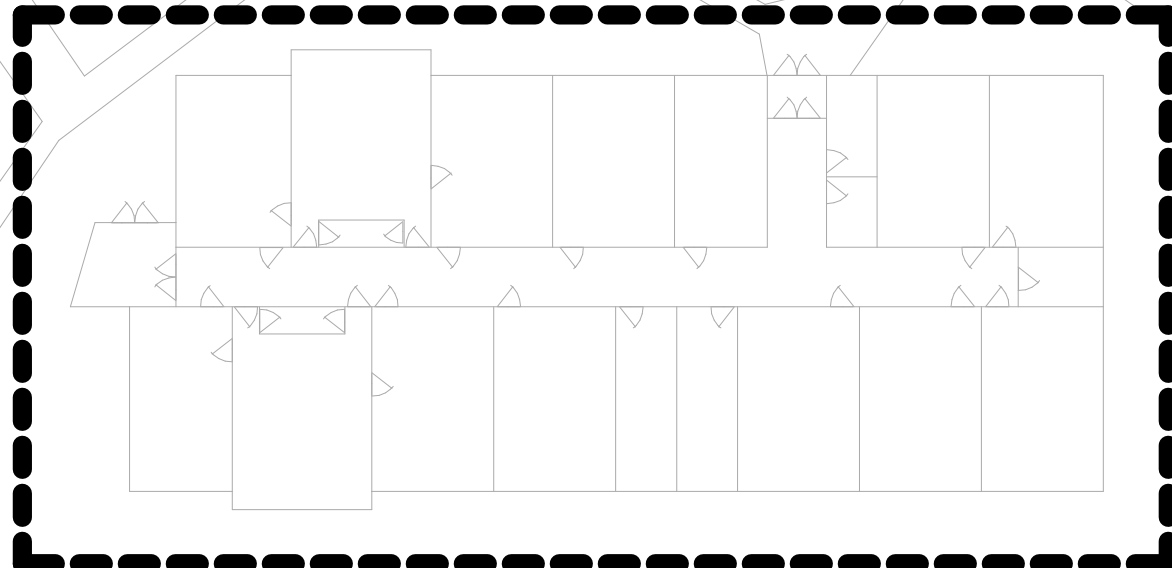

BUILDINGS A & B - REFER TO T128-T131

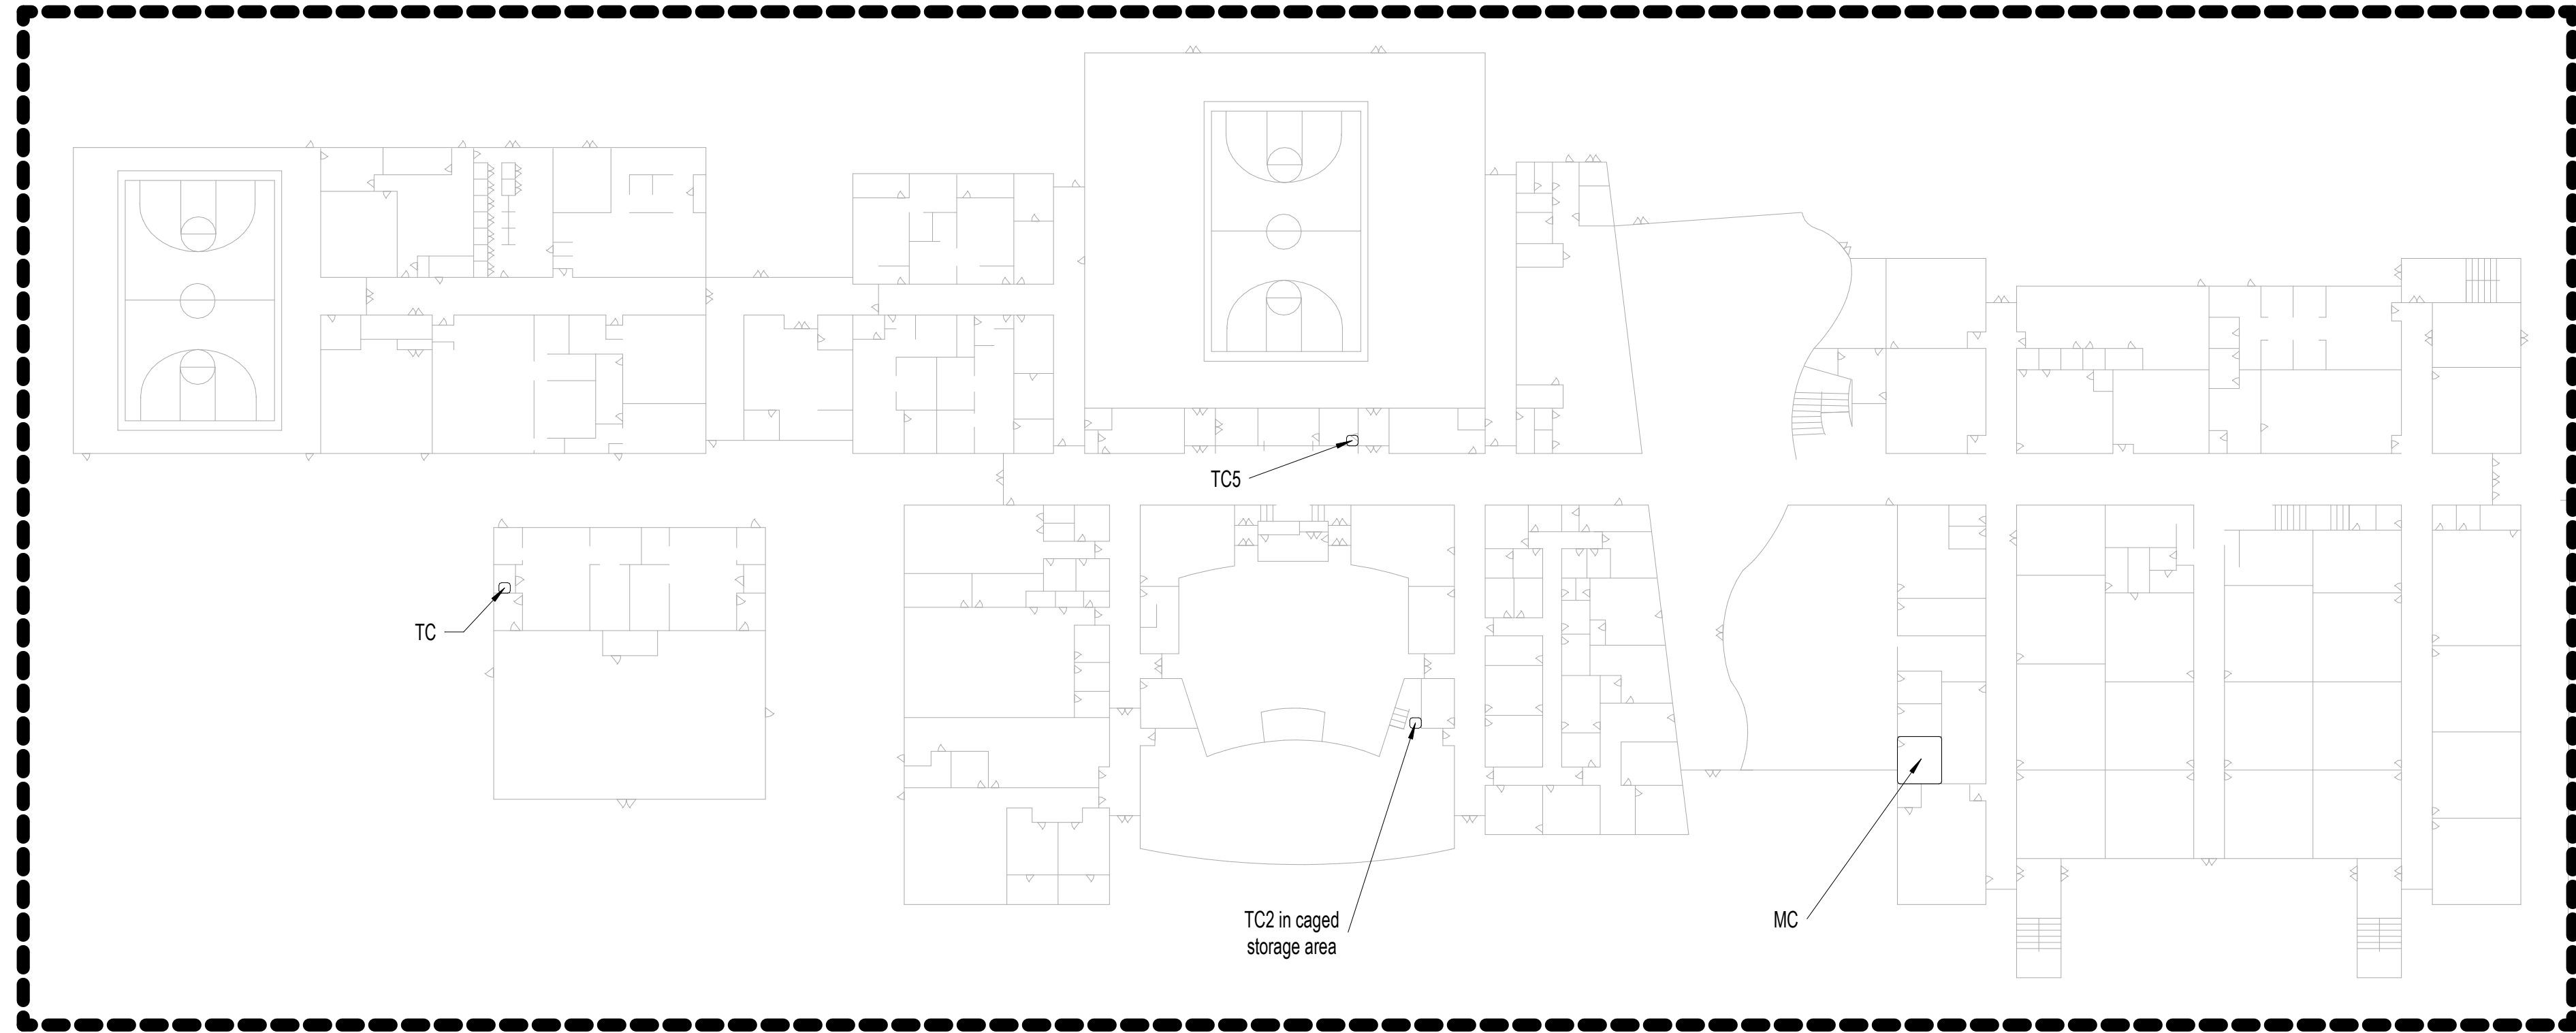

1 OVERALL FLOOR PLAN - LAKE VIEW HS - FIRST FLOOR
T115 1" = 50'-0"

Description

Date

Revision

Project



OVERALL FLOOR PLAN -
LAKE VIEW HS

Job No.

D-SAN-1003-01

Drawn By:

CV

Designed By:

CV

Date:



04/29/2026

Sheet No.

T115

Autodesk Docs\\CRUX\\San Angelo ISD Paging System Upgrade\\D-SAN-1003-01 SANSD HS_Paging Upgrade_Tech_02\\HOSTED.rvt

1 FIRST FLOOR LAKE VIEW HS - BUILDING A & B - AREA A
T116 1/16" = 1'-0"

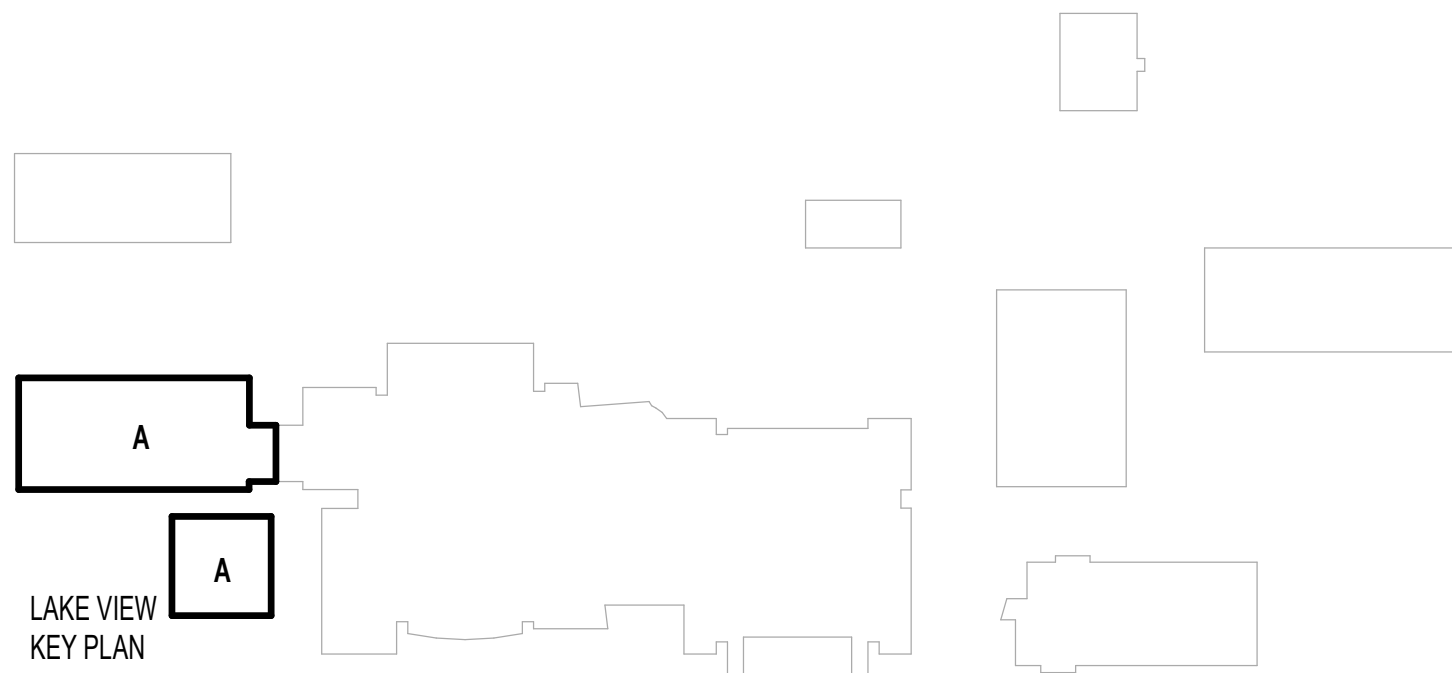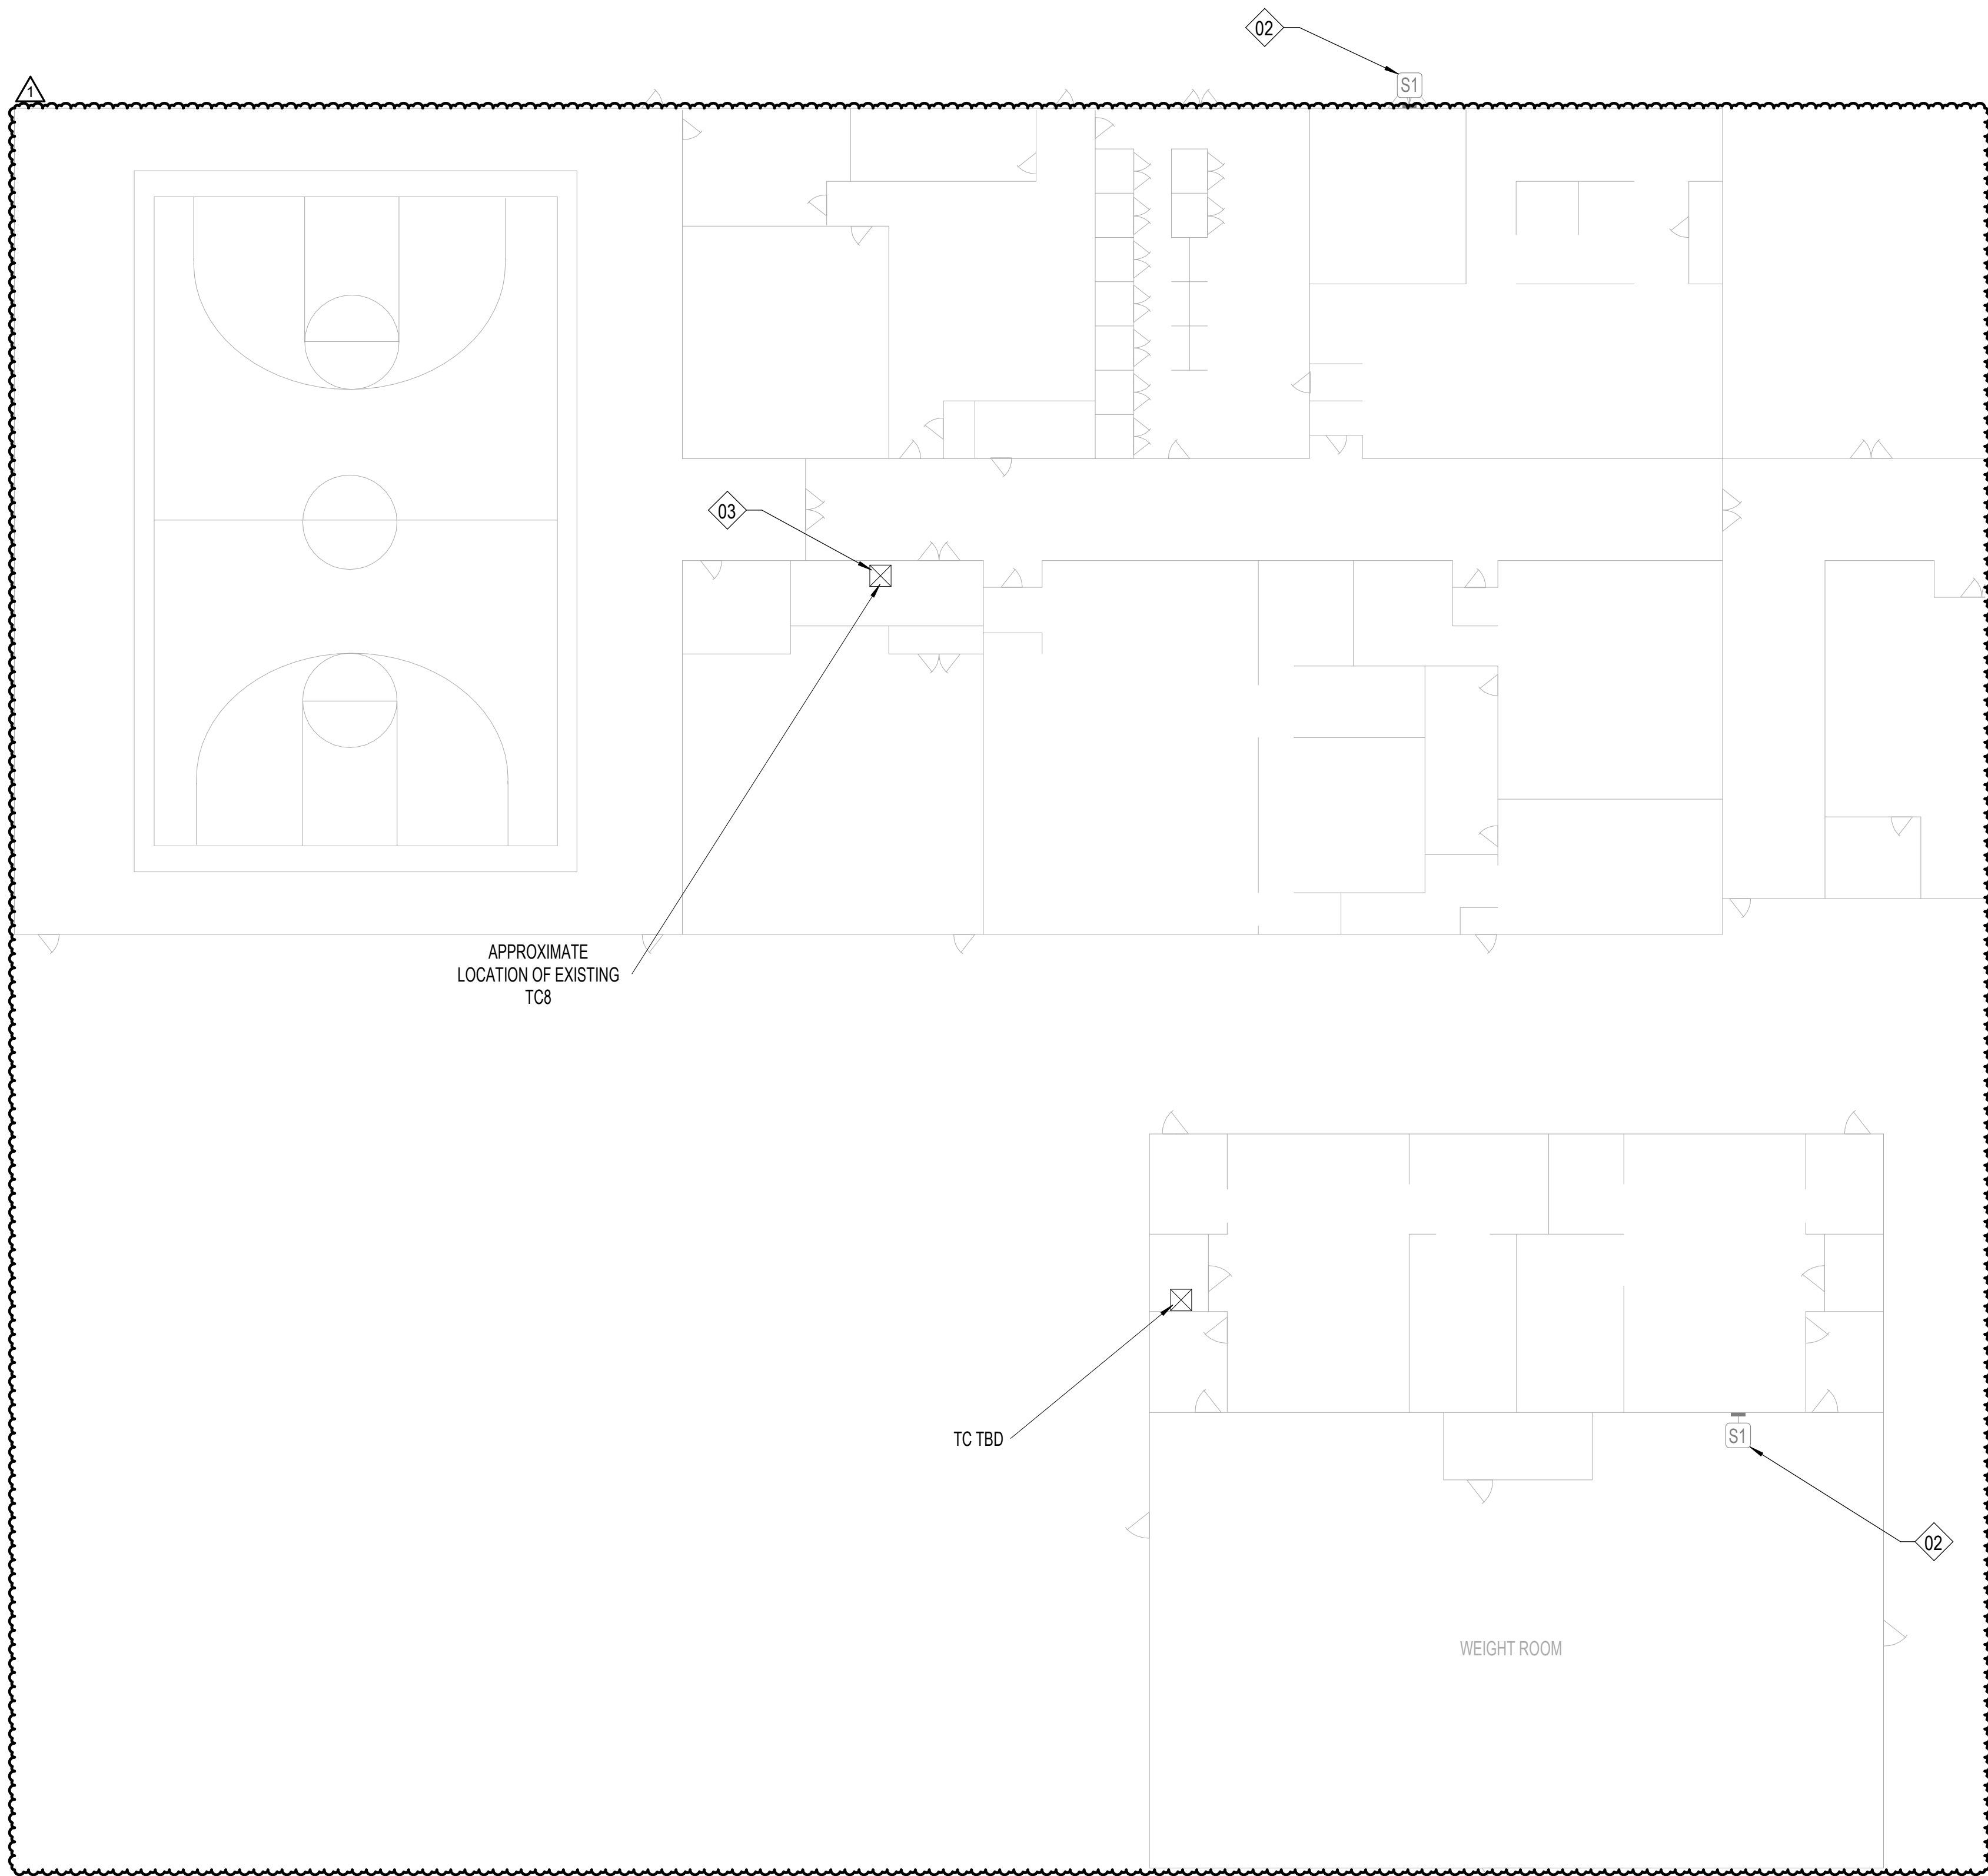

SHEET NOTES:

REFERENCE SHEET TG101 FOR ALL SYMBOLS AND PROJECT SPECIFIC NOTES.

EXISTING PAGING SPEAKERS (S1) ARE SHOWN IN HALF-TONE. CONTRACTOR SHALL REMOVE EXISTING PAGING SPEAKERS (S1) AND REPLACE WITH CEILING TILE OR BLANK COVER PLATE, UNO.

ALL CONDUITS SHALL BE 1" FOR ALL DEVICES UNLESS NOTED OTHERWISE ON THE TECHNOLOGY DRAWINGS.

IN AREAS WITH CONCRETE OR MASONRY WALLS, CONTRACTOR SHALL PROVIDE SURFACE RACEWAY SYSTEM.

IN AREAS WITH EXPOSED CEILINGS, CONTRACTOR SHALL INSTALL ALL CABLING IN CONDUIT. CONTRACTOR TO PERFORM PAINT FINISH AS COORDINATED WITH OWNER.

CONTRACTOR SHALL DEMOLISH ANY UNUSED CABLING BACK TO ITS ORIGIN AND DISPOSE.

CONTRACTOR SHALL REPLACE ALL EXISTING PTT BUTTONS PRESENT IN THE FACILITY WITH A BLANK COVER PLATE. CONTRACTOR SHALL LOCATE, DOCUMENT AND REMEDIATE IN THE SAME METHOD ANY PTT BUTTON NOT EXPLICITLY SHOWN IN THIS DRAWING SET.

CONTRACTOR IS RESPONSIBLE FOR PROVIDING LIFT FOR ALL HIGH CEILING AREAS (FINE ARTS, GYM, ETC.). CONTRACTOR SHALL ALSO BE REQUIRED TO PROVIDE FLOORING PROTECTION.

KEYNOTE LEGEND

(NOT ALL KEYNOTES MAY APPLY.)

01. EXISTING, CONTRACTOR SHALL REPLACE WITH NEW DEVICE AND NEW CABLING. CEILING TILE MAY REMAIN IN PLACE UNLESS DAMAGED.

02. EXISTING, TO REMAIN. CONTRACTOR SHALL INSTALL BRIDGE FROM ANALOG SPEAKER TO IP HEAD END.

03. CONTRACTOR SHALL COMPLETELY REMOVE ALL ABANDONED ANALOG SPEAKER WIRING AND SUPPORTING TERMINAL BLOCKS FROM THE FACILITY. TERMINAL BLOCKS THAT SUPPORT OTHER EXISTING DEVICES SHALL REMAIN.

04. INSTALL PLASTIC 1/2" RACEWAY FOR PATCH CABLE TO TOP OF SURFACE MOUNTED CLOCK BACK BOX. TERMINATE DATA ABOVE CEILING.

05. EXISTING, CONTRACTOR SHALL REMOVE DEVICE, DEMOLISH CABLING BACK TO ITS ORIGIN, AND INSTALL NEW BLANK FACEPLATE.

06. INSTALL DATA IN ADJACENT OVERHEAD CEILING SPACE. PROVIDE 1" SLEEVE THROUGH CMU WALL TO BACK OF CLOCK DISPLAY.

07. SURFACE MOUNTED CONDUIT NEEDED FOR ALL NEW PAGING AND RELATED DEVICES.

08. PROVIDE 1" CONDUIT TO TOP OF SURFACE MOUNTED CLOCK BACK BOX FOR PATCH CABLE. DATA SHALL BE TERMINATED ABOVE CEILING.

09. INSTALL SURFACE MOUNTED RACEWAY FROM DEVICE BACK TO TECH CLOSET LOCATION.

10. CEILING SPEAKER IN CAN MOUNTED TO STRUCTURAL STEEL.

11. THIS IS A PLASTER CEILING, CONDUIT OR PLASTIC RACEWAY WILL NEED TO BE SECURED TO THE CEILING ITSELF.

12. SPEAKERS MOUNTED TO STRUCTURAL STEEL.

13. INSTALL SURFACE RACEWAY FOR ENTIRE PATH FROM TC TO DEVICE.

14. EXISTING SPEAKER BUILT FLUSH IN WALL. DO NOT REMOVE. INSTALL NEW DEVICE ADJACENT TO EXISTING. INSTALL DATA DROP IN ACCESSIBLE CEILING IN ADJACENT SPACE.

15. REMOVE EXISTING HORNS AND LEAVE MOUNTS INTACT, REMOVE EXISTING CABLING. INSTALL NEW DUAL SIDED DEVICE ADJACENT TO FORMER HORN LOCATION. INSTALL DATA IN ADJACENT CEILING SPACE.

16. REFERENCE DIV 27 FOR RACK INFORMATION AND ALLOWANCE REQUIREMENTS. FINAL LOCATIONS TO BE COORDINATED WITH OWNER PRIOR TO INSTALLATION.

17. NOT USED.

18. RECENTLY INSTALLED SPEAKER, REMOVE, PROTECT, AND REDEPLOY WHERE OTHER NEW ANALOG CEILING SPEAKERS ARE NEEDED.

19. J-BOX LARGER THAN 4X4" NEEDED HERE. PROVIDE ADDITIONAL SLACK FOR FUTURE RETERMINATIONS.

20. FIELD CONDITIONS MAY DIFFER FROM WHAT IS SHOWN. COORDINATE EXACT LOCATION WITH OWNER.

21. GYP CEILING. CONTRACTOR SHALL ACCOUNT FOR THREE (3) 24"x24" ACCESS PANEL LOCATIONS IN PRICING. VERIFY PATHWAYS ON SITE.

Description

Addendum 01

Date:

05/18/25

Revision:

1

Project:

SAN ANGELO ISD
PAGING UPGRADE
SAN ANGELO, TEXAS
D-SAN-1003-01



CRUX
TECHNOLOGY • SECURITY SOLUTIONS
800.665.6440
www.cruxsolutions.com

FLOOR PLAN - LAKE VIEW
HS - FIRST FLOOR -
BUILDING A & B - AREA A

Job No.

D-SAN-1003-01

Drawn By:

CV

Designed By:

CV


Date:

04/29/2025

Sheet No.

T116

Autodesk Docs\CRUX-San Angelo ISD Paging System Upgrade\B SAN-1003-01 SANSD HS_Paging Upgrade_Tech_02\HOSTED.rvt

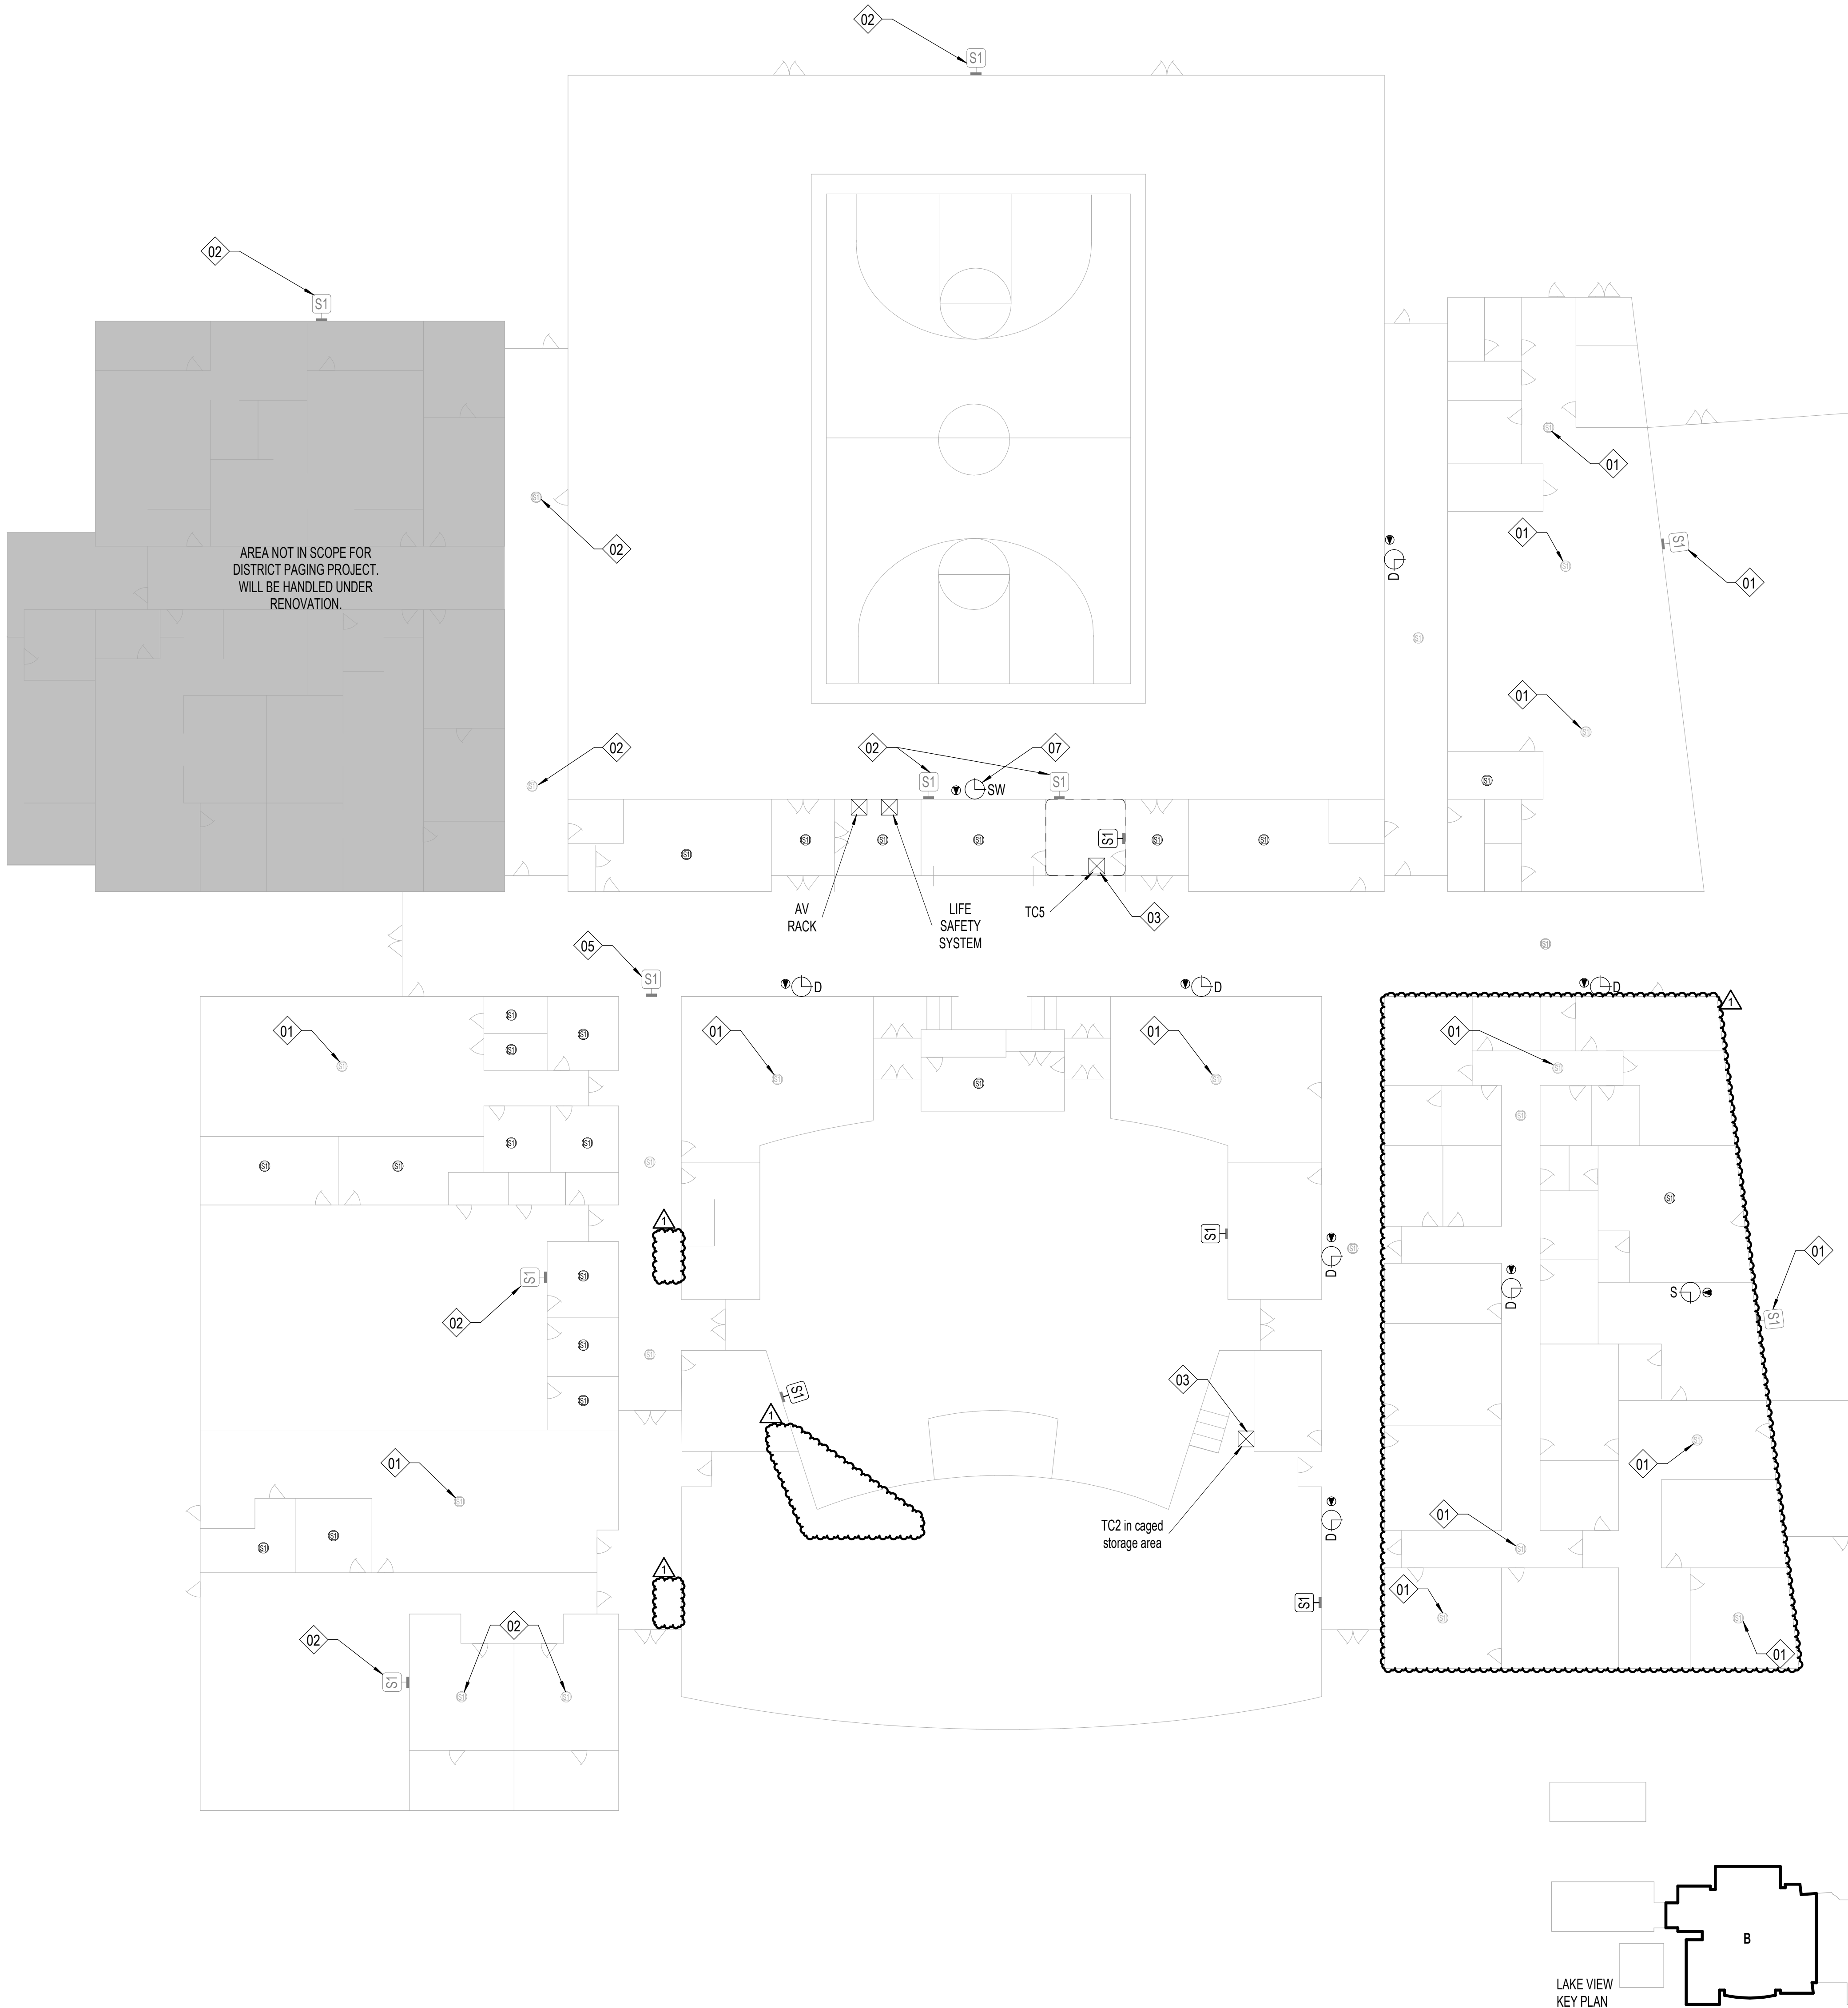

SHEET NOTES:

REFERENCE SHEET TG101 FOR ALL SYMBOLS AND PROJECT SPECIFIC NOTES.

EXISTING PAGING SPEAKERS (S1) ARE SHOWN IN HALF-TONE. CONTRACTOR SHALL REMOVE EXISTING PAGING SPEAKERS (S1) AND REPLACE WITH CEILING TILE OR BLANK COVER PLATE, UNO.

ALL CONDUITS SHALL BE 1" FOR ALL DEVICES UNLESS NOTED OTHERWISE ON THE TECHNOLOGY DRAWINGS.

IN AREAS WITH CONCRETE OR MASONRY WALLS, CONTRACTOR SHALL PROVIDE SURFACE RACEWAY SYSTEM.

IN AREAS WITH EXPOSED CEILINGS, CONTRACTOR SHALL INSTALL ALL CABLING IN CONDUIT. CONTRACTOR TO PERFORM PAINT FINISH AS COORDINATED WITH OWNER.

CONTRACTOR SHALL DEMOLISH ANY UNUSED CABLING BACK TO ITS ORIGIN AND DISPOSE.

CONTRACTOR SHALL REPLACE ALL EXISTING PTT BUTTONS PRESENT IN THE FACILITY WITH A BLANK COVER PLATE. CONTRACTOR SHALL LOCATE, DOCUMENT AND REMEDIATE IN THE SAME METHOD ANY PTT BUTTON NOT EXPLICITLY SHOWN IN THIS DRAWING SET.

CONTRACTOR IS RESPONSIBLE FOR PROVIDING LIFT FOR ALL HIGH CEILING AREAS (FINE ARTS, GYM, ETC.). CONTRACTOR SHALL ALSO BE REQUIRED TO PROVIDE FLOORING PROTECTION.

KEYNOTE LEGEND

(NOT ALL KEYNOTES MAY APPLY)

01. EXISTING, CONTRACTOR SHALL REPLACE WITH NEW DEVICE AND NEW CABLING. CEILING TILE MAY REMAIN IN PLACE UNLESS DAMAGED.

02. EXISTING, TO REMAIN. CONTRACTOR SHALL INSTALL BRIDGE FROM ANALOG SPEAKER TO IP HEAD END.

03. CONTRACTOR SHALL COMPLETELY REMOVE ALL ABANDONED ANALOG SPEAKER WIRING AND SUPPORTING TERMINAL BLOCKS FROM THE FACILITY. TERMINAL BLOCKS THAT SUPPORT OTHER EXISTING DEVICES SHALL REMAIN.

04. INSTALL PLASTIC 1/2" RACEWAY FOR PATCH CABLE TO TOP OF SURFACE MOUNTED CLOCK BACK BOX. TERMINATE DATA ABOVE CEILING.

05. EXISTING, CONTRACTOR SHALL REMOVE DEVICE, DEMOLISH CABLING BACK TO ITS ORIGIN, AND INSTALL NEW BLANK FACEPLATE.

06. INSTALL DATA IN ADJACENT OVERHEAD CEILING SPACE. PROVIDE 1" SLEEVE THROUGH CMU WALL TO BACK OF CLOCK DISPLAY.

07. SURFACE MOUNTED CONDUIT NEEDED FOR ALL NEW PAGING AND RELATED DEVICES.

08. PROVIDE 1" CONDUIT TO TOP OF SURFACE MOUNTED CLOCK BACK BOX FOR PATCH CABLE. DATA SHALL BE TERMINATED ABOVE CEILING.

09. INSTALL SURFACE MOUNTED RACEWAY FROM DEVICE BACK TO TECH CLOSET LOCATION.

10. CEILING SPEAKER IN CAN MOUNTED TO STRUCTURAL STEEL.

11. THIS IS A PLASTER CEILING, CONDUIT OR PLASTIC RACEWAY WILL NEED TO BE SECURED TO THE CEILING ITSELF.

12. SPEAKERS MOUNTED TO STRUCTURAL STEEL.

13. INSTALL SURFACE RACEWAY FOR ENTIRE PATH FROM TC TO DEVICE.

14. EXISTING SPEAKER BUILT FLUSH IN WALL. DO NOT REMOVE. INSTALL NEW DEVICE ADJACENT TO EXISTING. INSTALL DATA DROP IN ACCESSIBLE CEILING IN ADJACENT SPACE.

15. REMOVE EXISTING HORNS AND LEAVE MOUNTS INTACT, REMOVE EXISTING CABLING. INSTALL NEW DUAL SIDED DEVICE ADJACENT TO FORMER HORN LOCATION. INSTALL DATA IN ADJACENT CEILING SPACE.

16. REFERENCE DIV 27 FOR RACK INFORMATION AND ALLOWANCE REQUIREMENTS. FINAL LOCATIONS TO BE COORDINATED WITH OWNER PRIOR TO INSTALLATION.

17. NOT USED.

18. RECENTLY INSTALLED SPEAKER, REMOVE, PROTECT, AND REDEPLOY WHERE OTHER NEW ANALOG CEILING SPEAKERS ARE NEEDED.

19. J-BOX LARGER THAN 4X4" NEEDED HERE. PROVIDE ADDITIONAL SLACK FOR FUTURE RETERMINATIONS.

20. FIELD CONDITIONS MAY DIFFER FROM WHAT IS SHOWN. COORDINATE EXACT LOCATION WITH OWNER.

21. GYP CEILING. CONTRACTOR SHALL ACCOUNT FOR THREE (3) 24"x24" ACCESS PANEL LOCATIONS IN PRICING. VERIFY PATHWAYS ON SITE.

1 FIRST FLOOR LAKE VIEW HS - BUILDING A - AREA B
1/16" = 1'-0"

Description

Addendum 01

Date: 05/18/25

Revision: 1

Project:

SAN ANGELO ISD
PAGING UPGRADE
SAN ANGELO, TEXAS
D-SAN-1003-01



CRUX
TECHNOLOGY • SECURITY SOLUTIONS
800.665.6440
www.cruxsolutions.com

FLOOR PLAN - LAKE VIEW
HS - FIRST FLOOR -
BUILDING A - AREA B

Job No.

D-SAN-1003-01

Drawn By:

CV

Designed By:

CV


Date:

04/29/2025

Sheet No.

T117

Autodesk Docs\CRUX-San Angelo ISD Paging System Upgrade\B SAN-1003-01 SANSD ISD Paging Upgrade, TECH, 02\HOSTED.rvt

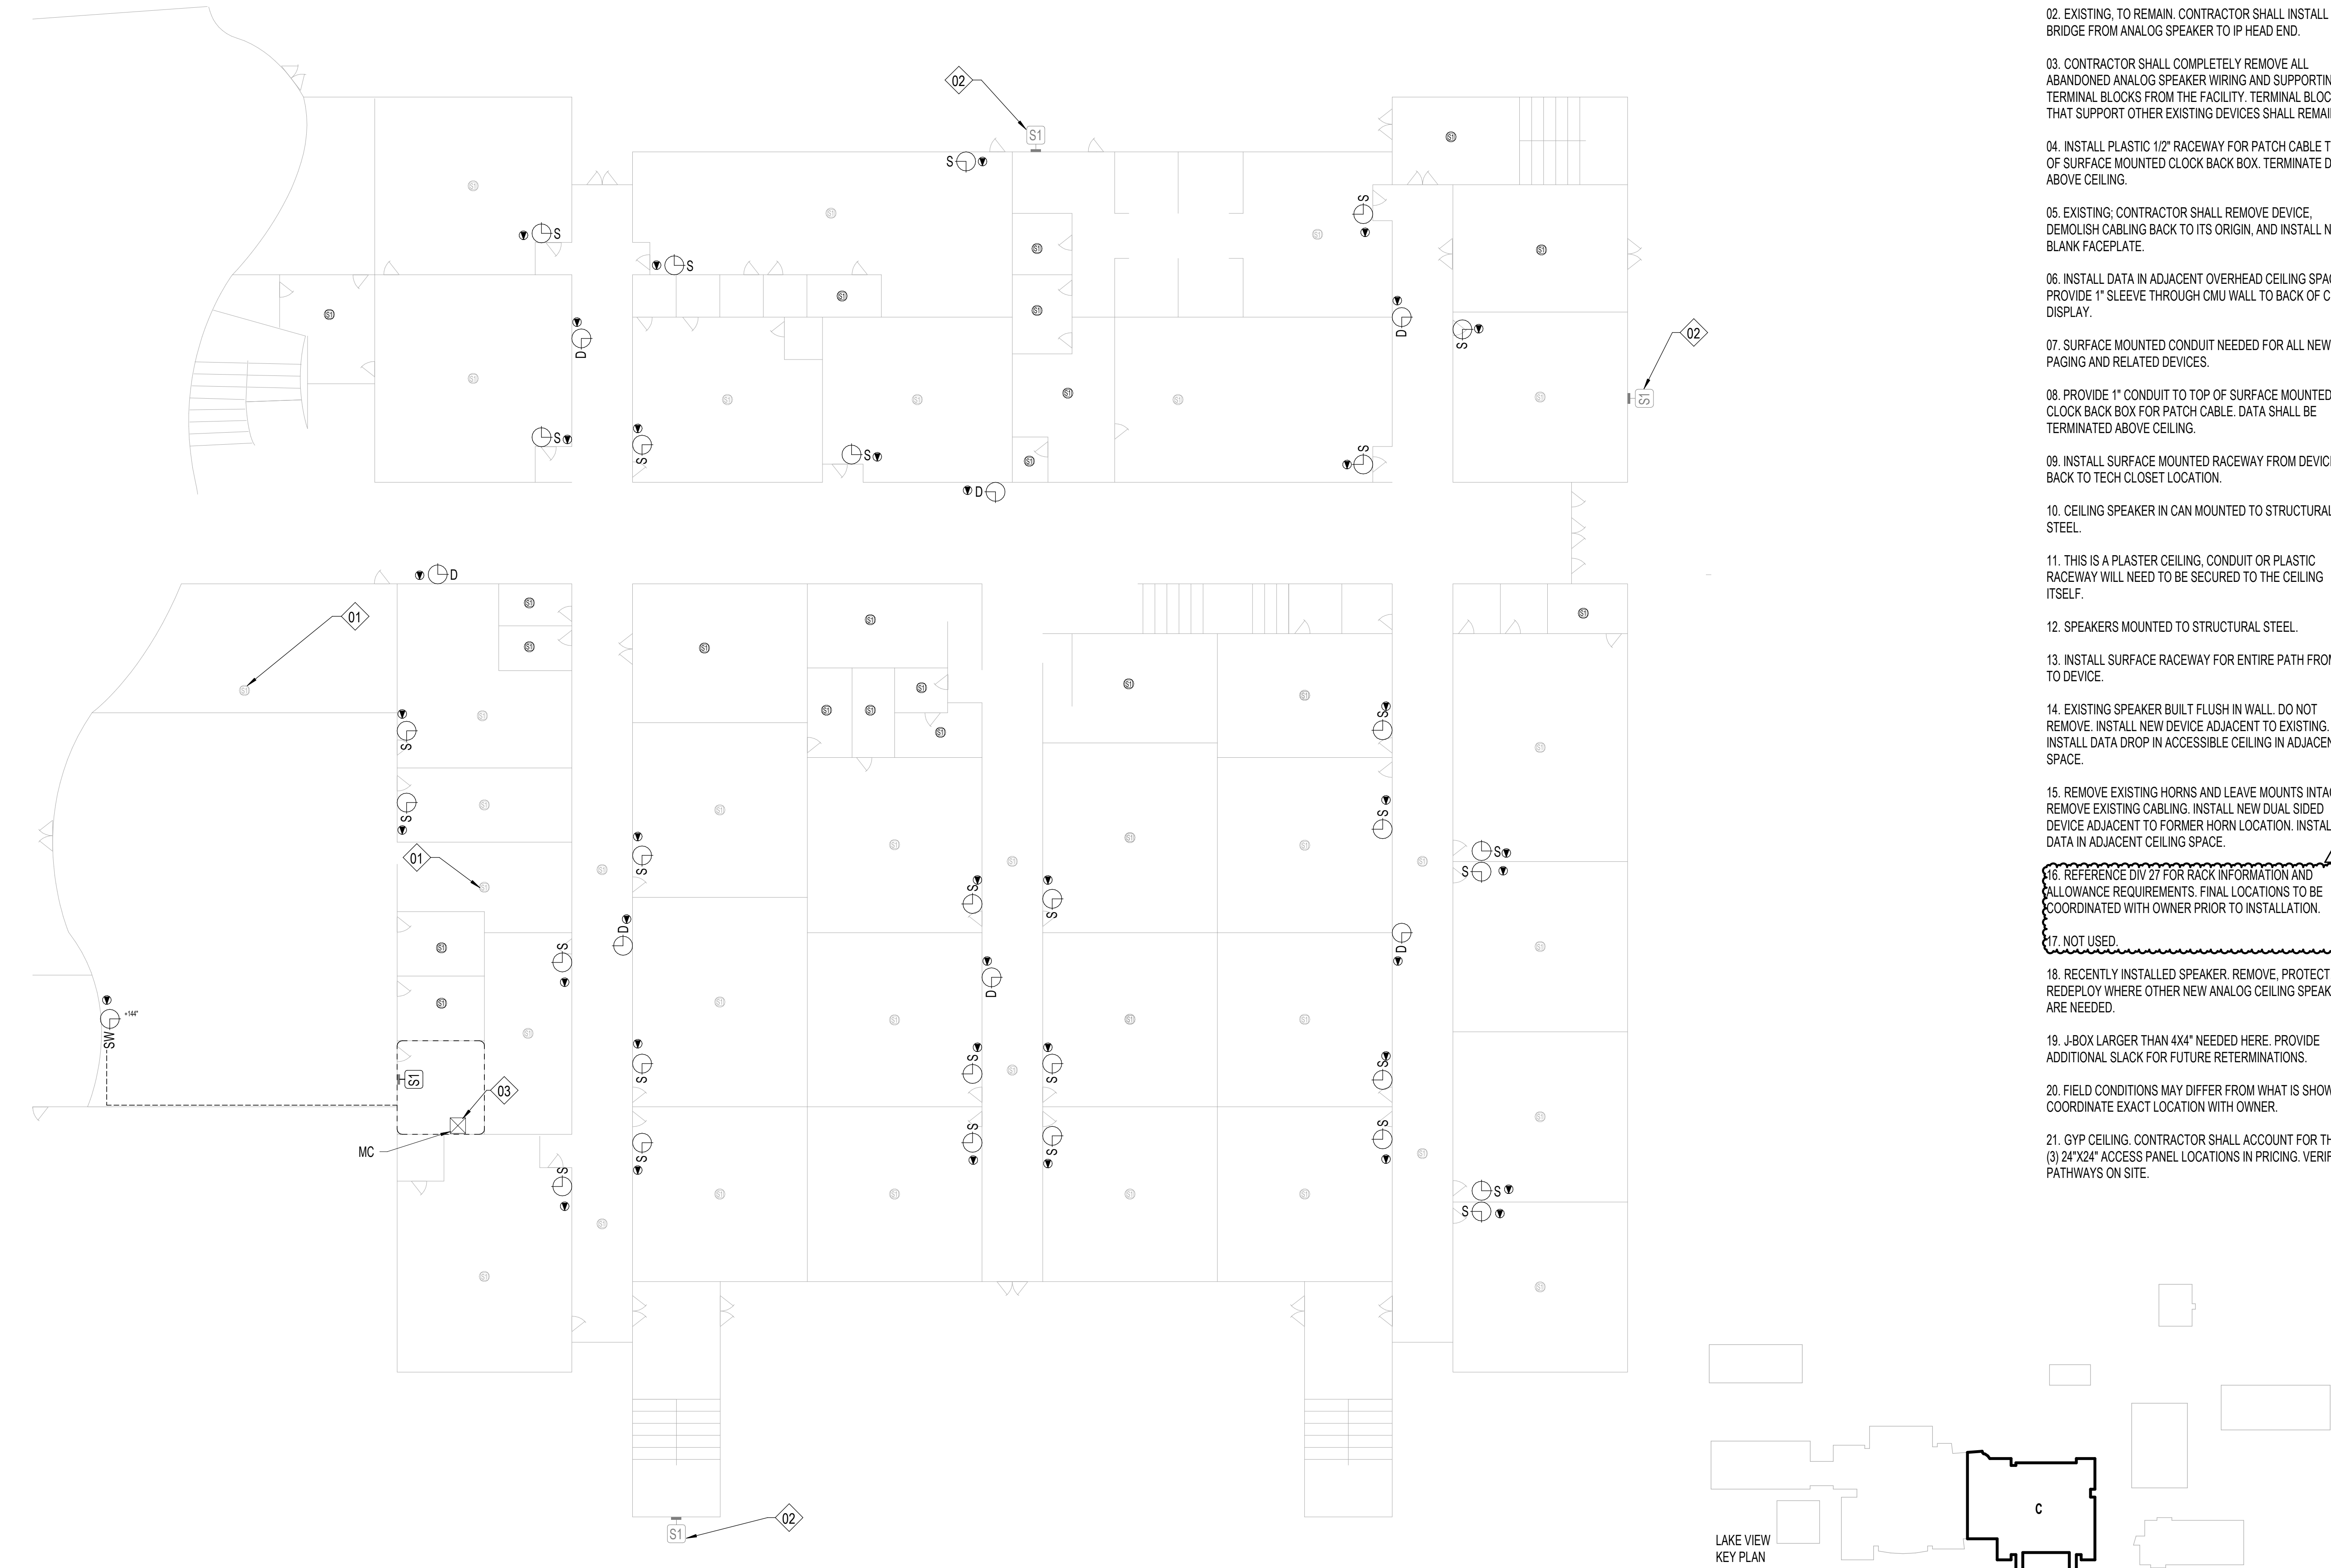

1 FIRST FLOOR LAKE VIEW HS - BUILDING A - AREA C
T118 1/16" = 1'-0"

SHEET NOTES:

REFERENCE SHEET TG101 FOR ALL SYMBOLS AND PROJECT SPECIFIC NOTES.

EXISTING PAGING SPEAKERS (S1) ARE SHOWN IN HALF-TONE. CONTRACTOR SHALL REMOVE EXISTING PAGING SPEAKERS (S1) AND REPLACE WITH CEILING TILE OR BLANK COVER PLATE, UNO.

ALL CONDUITS SHALL BE 1" FOR ALL DEVICES UNLESS NOTED OTHERWISE ON THE TECHNOLOGY DRAWINGS.

IN AREAS WITH CONCRETE OR MASONRY WALLS, CONTRACTOR SHALL PROVIDE SURFACE RACEWAY SYSTEM.

IN AREAS WITH EXPOSED CEILINGS, CONTRACTOR SHALL INSTALL ALL CABLING IN CONDUIT. CONTRACTOR TO PERFORM PAINT FINISH AS COORDINATED WITH OWNER.

CONTRACTOR SHALL DEMOLISH ANY UNUSED CABLING BACK TO ITS ORIGIN AND DISPOSE.

CONTRACTOR SHALL REPLACE ALL EXISTING PTT BUTTONS PRESENT IN THE FACILITY WITH A BLANK COVER PLATE. CONTRACTOR SHALL LOCATE, DOCUMENT AND REMEDIATE IN THE SAME METHOD ANY PTT BUTTON NOT EXPLICITLY SHOWN IN THIS DRAWING SET.

CONTRACTOR IS RESPONSIBLE FOR PROVIDING LIFT FOR ALL HIGH CEILING AREAS (FINE ARTS, GYM, ETC.). CONTRACTOR SHALL ALSO BE REQUIRED TO PROVIDE FLOORING PROTECTION.

KEYNOTE LEGEND

(NOT ALL KEYNOTES MAY APPLY.)

01. EXISTING, CONTRACTOR SHALL REPLACE WITH NEW DEVICE AND NEW CABLING. CEILING TILE MAY REMAIN IN PLACE UNLESS DAMAGED.

02. EXISTING, TO REMAIN. CONTRACTOR SHALL INSTALL BRIDGE FROM ANALOG SPEAKER TO IP HEAD END.

03. CONTRACTOR SHALL COMPLETELY REMOVE ALL ABANDONED ANALOG SPEAKER WIRING AND SUPPORTING TERMINAL BLOCKS FROM THE FACILITY. TERMINAL BLOCKS THAT SUPPORT OTHER EXISTING DEVICES SHALL REMAIN.

04. INSTALL PLASTIC 1/2" RACEWAY FOR PATCH CABLE TO TOP OF SURFACE MOUNTED CLOCK BACK BOX. TERMINATE DATA ABOVE CEILING.

05. EXISTING, CONTRACTOR SHALL REMOVE DEVICE, DEMOLISH CABLING BACK TO ITS ORIGIN, AND INSTALL NEW BLANK FACEPLATE.

06. INSTALL DATA IN ADJACENT OVERHEAD CEILING SPACE. PROVIDE 1" SLEEVE THROUGH CMU WALL TO BACK OF CLOCK DISPLAY.

07. SURFACE MOUNTED CONDUIT NEEDED FOR ALL NEW PAGING AND RELATED DEVICES.

08. PROVIDE 1" CONDUIT TO TOP OF SURFACE MOUNTED CLOCK BACK BOX FOR PATCH CABLE. DATA SHALL BE TERMINATED ABOVE CEILING.

09. INSTALL SURFACE MOUNTED RACEWAY FROM DEVICE BACK TO TECH CLOSET LOCATION.

10. CEILING SPEAKER IN CAN MOUNTED TO STRUCTURAL STEEL.

11. THIS IS A PLASTER CEILING, CONDUIT OR PLASTIC RACEWAY WILL NEED TO BE SECURED TO THE CEILING ITSELF.

12. SPEAKERS MOUNTED TO STRUCTURAL STEEL.

13. INSTALL SURFACE RACEWAY FOR ENTIRE PATH FROM TC TO DEVICE.

14. EXISTING SPEAKER BUILT FLUSH IN WALL. DO NOT REMOVE. INSTALL NEW DEVICE ADJACENT TO EXISTING. INSTALL DATA DROP IN ACCESSIBLE CEILING IN ADJACENT SPACE.

15. REMOVE EXISTING HORNS AND LEAVE MOUNTS INTACT. REMOVE EXISTING CABLING. INSTALL NEW DUAL SIDED DEVICE ADJACENT TO FORMER HORN LOCATION. INSTALL DATA IN ADJACENT CEILING SPACE.

16. REFERENCE DIV 27 FOR RACK INFORMATION AND ALLOWANCE REQUIREMENTS. FINAL LOCATIONS TO BE COORDINATED WITH OWNER PRIOR TO INSTALLATION.

17. NOT USED.

18. RECENTLY INSTALLED SPEAKER. REMOVE, PROTECT, AND REDEPLOY WHERE OTHER NEW ANALOG CEILING SPEAKERS ARE NEEDED.

19. J-BOX LARGER THAN 4X4" NEEDED HERE. PROVIDE ADDITIONAL SLACK FOR FUTURE RETERMINATIONS.

20. FIELD CONDITIONS MAY DIFFER FROM WHAT IS SHOWN. COORDINATE EXACT LOCATION WITH OWNER.

21. GYP CEILING. CONTRACTOR SHALL ACCOUNT FOR THREE (3) 24"X24" ACCESS PANEL LOCATIONS IN PRICING. VERIFY PATHWAYS ON SITE.

Description

Date

Revision

Project

SAN ANGELO ISD
PAGING UPGRADE
SAN ANGELO, TEXAS
D-SAN-1003-01




CRUX
TECHNOLOGY • SECURITY SOLUTIONS
800.665.6440
www.cruxsolutions.com

FLOOR PLAN - LAKE VIEW
HS - FIRST FLOOR -
BUILDING A - AREA C

Job No.
D-SAN-1003-01
Drawn By:
CV
Designed By:
CV
Date:
04/29/2026
Sheet No.
T118

Autodesk Docs\CRUX-San Angelo ISD Paging System Upgrade\B SAN-1003-01 SANSD HS_Paging Upgrade_Tech_02\HOSTED.rvt

1 SECOND FLOOR LAKE VIEW HS - BUILDING A
T119 1/16" = 1'-0"

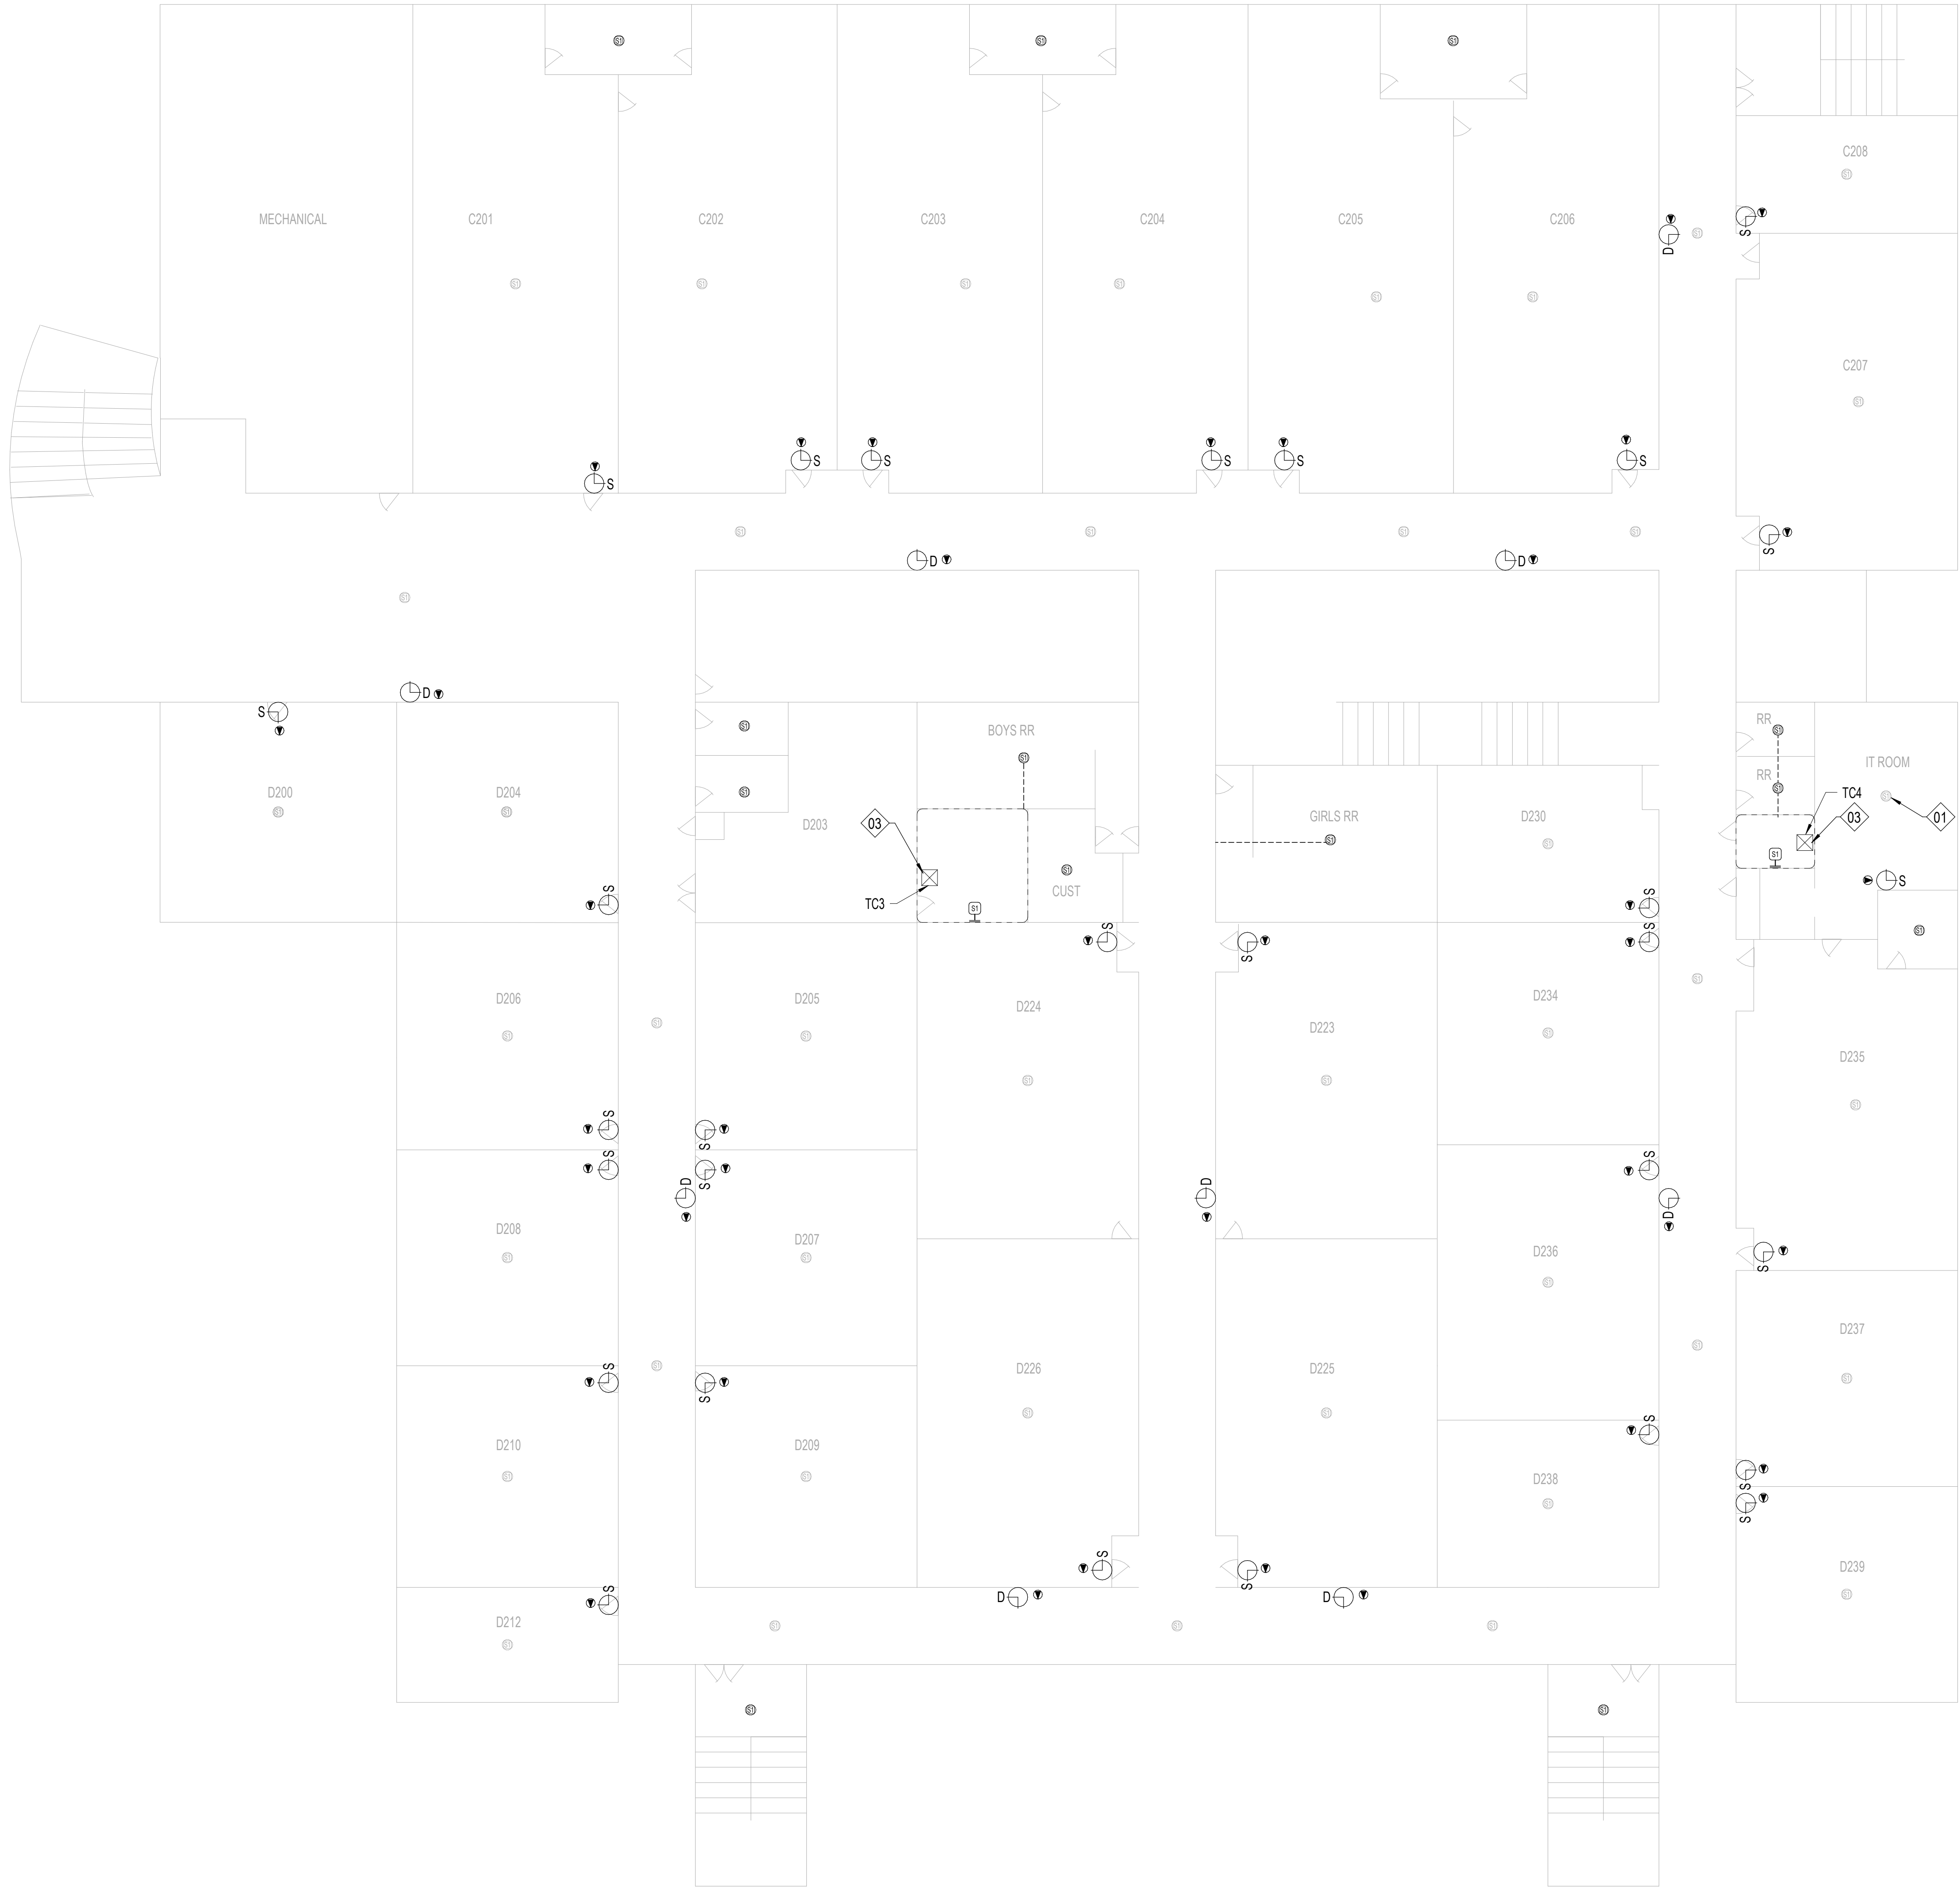

SHEET NOTES:

REFERENCE SHEET TG101 FOR ALL SYMBOLS AND PROJECT SPECIFIC NOTES.

EXISTING PAGING SPEAKERS (S1) ARE SHOWN IN HALF-TONE. CONTRACTOR SHALL REMOVE EXISTING PAGING SPEAKERS (S1) AND REPLACE WITH CEILING TILE OR BLANK COVER PLATE, UNLESS NOTED OTHERWISE.

ALL CONDUITS SHALL BE 1" FOR ALL DEVICES UNLESS NOTED OTHERWISE ON THE TECHNOLOGY DRAWINGS.

IN AREAS WITH CONCRETE OR MASONRY WALLS, CONTRACTOR SHALL PROVIDE SURFACE RACEWAY SYSTEM.

IN AREAS WITH EXPOSED CEILINGS, CONTRACTOR SHALL INSTALL ALL CABLING IN CONDUIT. CONTRACTOR TO PERFORM PAINT FINISH AS COORDINATED WITH OWNER.

CONTRACTOR SHALL DEMOLISH ANY UNUSED CABLING BACK TO ITS ORIGIN AND DISPOSE.


CONTRACTOR SHALL REPLACE ALL EXISTING PTT BUTTONS PRESENT IN THE FACILITY WITH A BLANK COVER PLATE. CONTRACTOR SHALL LOCATE, DOCUMENT AND REMEDIATE IN THE SAME METHOD ANY PTT BUTTON NOT EXPLICITLY SHOWN IN THIS DRAWING SET.

CONTRACTOR IS RESPONSIBLE FOR PROVIDING LIFT FOR ALL HIGH CEILING AREAS (FINE ARTS, GYM, ETC.). CONTRACTOR SHALL ALSO BE REQUIRED TO PROVIDE FLOORING PROTECTION.

KEYNOTE LEGEND

(NOT ALL KEYNOTES MAY APPLY.)

01. EXISTING, CONTRACTOR SHALL REPLACE WITH NEW DEVICE AND NEW CABLING. CEILING TILE MAY REMAIN IN PLACE UNLESS DAMAGED.
02. EXISTING, TO REMAIN. CONTRACTOR SHALL INSTALL BRIDGE FROM ANALOG SPEAKER TO IP HEAD END.
03. CONTRACTOR SHALL COMPLETELY REMOVE ALL ABANDONED ANALOG SPEAKER WIRING AND SUPPORTING TERMINAL BLOCKS FROM THE FACILITY. TERMINAL BLOCKS THAT SUPPORT OTHER EXISTING DEVICES SHALL REMAIN.
04. INSTALL PLASTIC 1/2" RACEWAY FOR PATCH CABLE TO TOP OF SURFACE MOUNTED CLOCK BACK BOX. TERMINATE DATA ABOVE CEILING.
05. EXISTING, CONTRACTOR SHALL REMOVE DEVICE, DEMOLISH CABLING BACK TO ITS ORIGIN, AND INSTALL NEW BLANK FACEPLATE.
06. INSTALL DATA IN ADJACENT OVERHEAD CEILING SPACE. PROVIDE 1" SLEEVE THROUGH CMU WALL TO BACK OF CLOCK DISPLAY.
07. SURFACE MOUNTED CONDUIT NEEDED FOR ALL NEW PAGING AND RELATED DEVICES.
08. PROVIDE 1" CONDUIT TO TOP OF SURFACE MOUNTED CLOCK BACK BOX FOR PATCH CABLE. DATA SHALL BE TERMINATED ABOVE CEILING.
09. INSTALL SURFACE MOUNTED RACEWAY FROM DEVICE BACK TO TECH CLOSET LOCATION.
10. CEILING SPEAKER IN CAN MOUNTED TO STRUCTURAL STEEL.
11. THIS IS A PLASTER CEILING, CONDUIT OR PLASTIC RACEWAY WILL NEED TO BE SECURED TO THE CEILING ITSELF.
12. SPEAKERS MOUNTED TO STRUCTURAL STEEL.
13. INSTALL SURFACE RACEWAY FOR ENTIRE PATH FROM TC TO DEVICE.
14. EXISTING SPEAKER BUILT FLUSH IN WALL. DO NOT REMOVE. INSTALL NEW DEVICE ADJACENT TO EXISTING. INSTALL DATA DROP IN ACCESSIBLE CEILING IN ADJACENT SPACE.
15. REMOVE EXISTING HORNS AND LEAVE MOUNTS INTACT, REMOVE EXISTING CABLING. INSTALL NEW DUAL SIDED DEVICE ADJACENT TO FORMER HORN LOCATION. INSTALL DATA IN ADJACENT CEILING SPACE.
16. REFERENCE DIV 27 FOR RACK INFORMATION AND ALLOWANCE REQUIREMENTS. FINAL LOCATIONS TO BE COORDINATED WITH OWNER PRIOR TO INSTALLATION.
17. NOT USED.
18. RECENTLY INSTALLED SPEAKER, REMOVE, PROTECT, AND REDEPLOY WHERE OTHER NEW ANALOG CEILING SPEAKERS ARE NEEDED.
19. J-BOX LARGER THAN 4X4" NEEDED HERE. PROVIDE ADDITIONAL SLACK FOR FUTURE RETERMINATIONS.
20. FIELD CONDITIONS MAY DIFFER FROM WHAT IS SHOWN. COORDINATE EXACT LOCATION WITH OWNER.
21. GYP CEILING. CONTRACTOR SHALL ACCOUNT FOR THREE (3) 24"x24" ACCESS PANEL LOCATIONS IN PRICING. VERIFY PATHWAYS ON SITE.

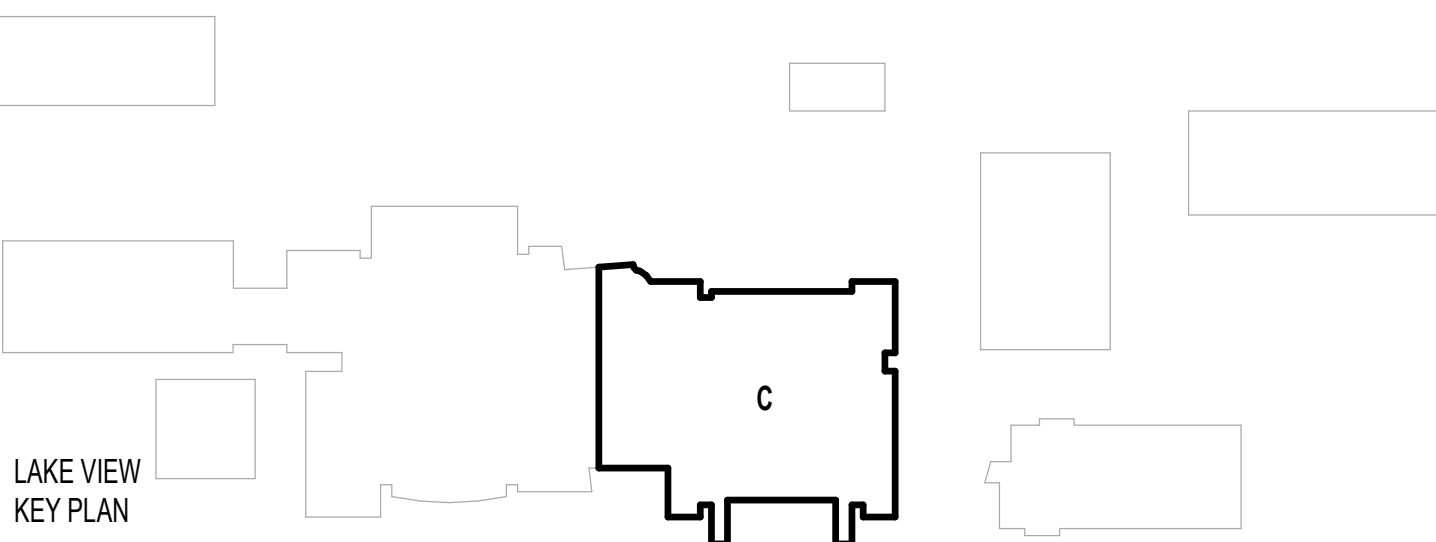

Description

Date:

Revision:

Project:

SAN ANGELO ISD
PAGING UPGRADE
SAN ANGELO, TEXAS
D-SAN-1003-01



CRUX
TECHNOLOGY • SECURITY SOLUTIONS
800.665.6440
www.cruxsolutions.com


FLOOR PLAN - LAKE VIEW
HS - SECOND FLOOR -
BUILDING A - AREA C

Job No.
D-SAN-1003-01
Drawn By:
CV
Designed By:
CV
Date:
04/29/2026


Sheet No.

T119

Autodesk Docs\CRUX-San Angelo ISD Paging System Upgrade\B SAN-1003-01 SANSD ISD_Paging Upgrade_Tech_02(HOSTED).rvt

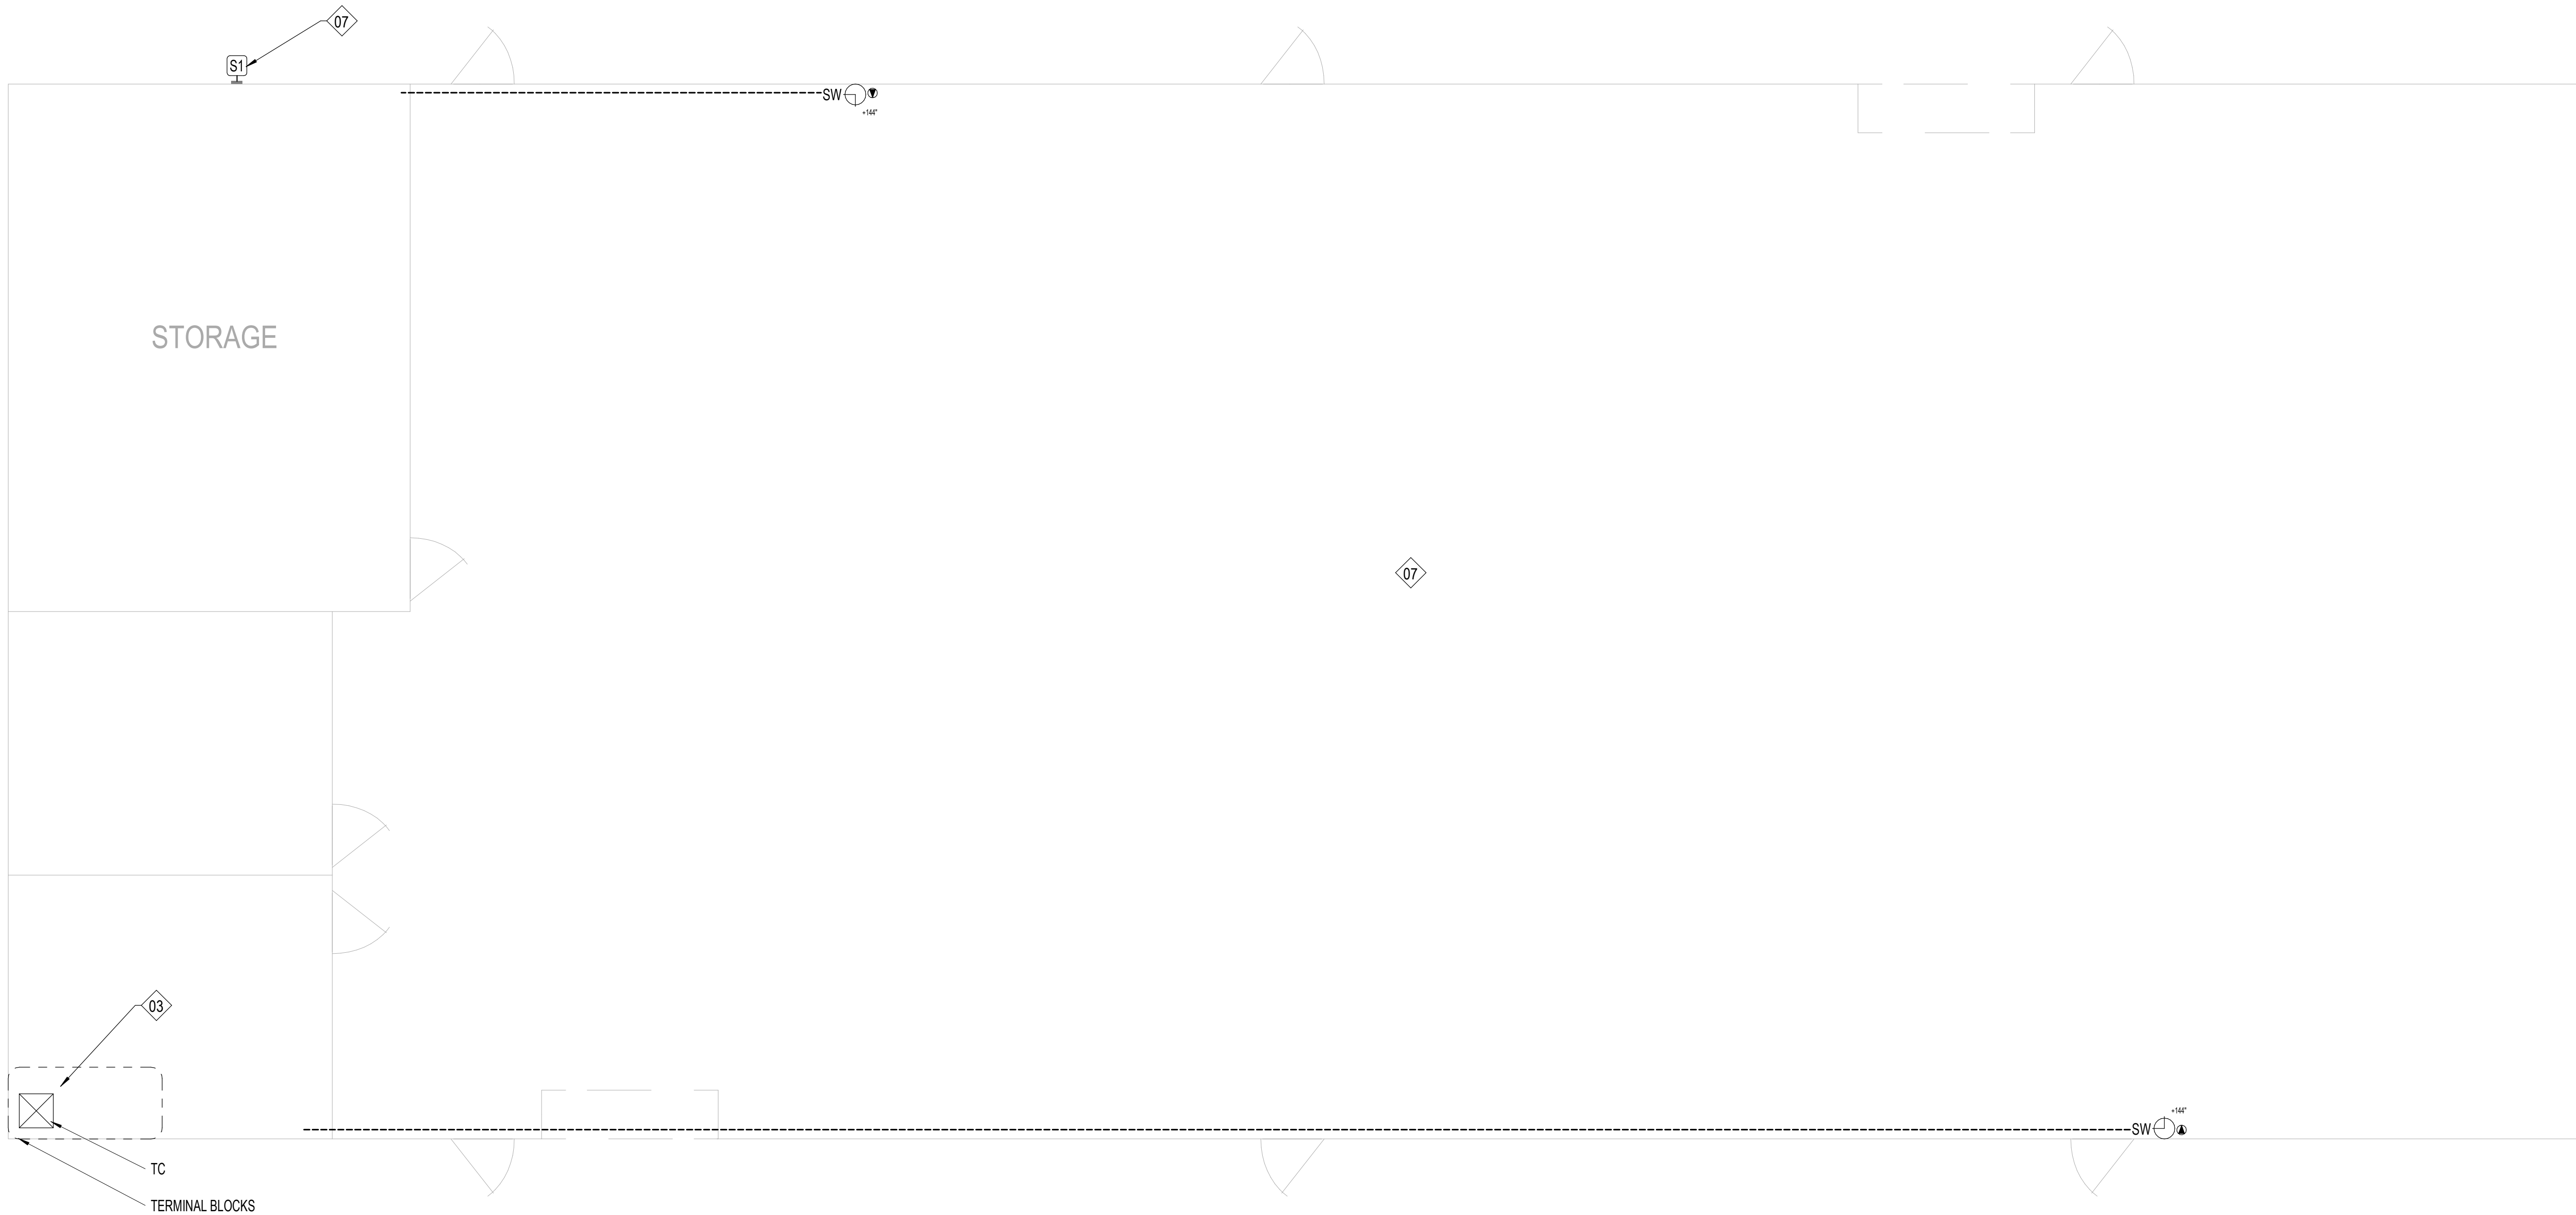

1 FLOOR PLAN - LAKE VIEW HS - BUILDING C
T120 1/8" = 1'-0"

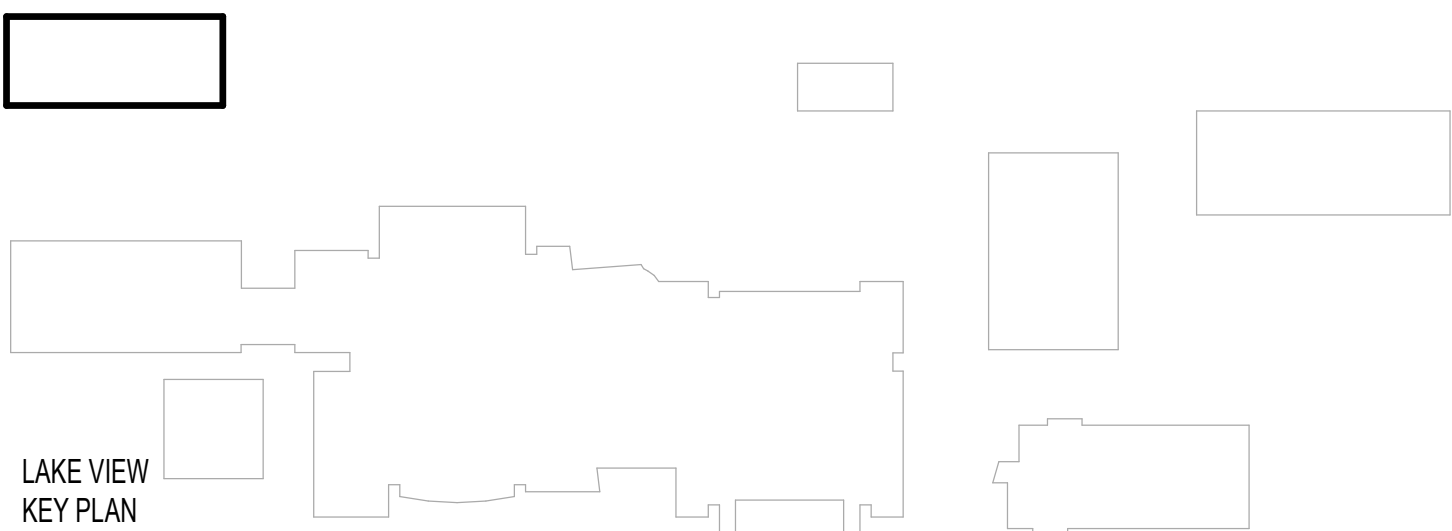

SHEET NOTES:

REFERENCE SHEET TG101 FOR ALL SYMBOLS AND PROJECT SPECIFIC NOTES.

EXISTING PAGING SPEAKERS (S1) ARE SHOWN IN HALF-TONE. CONTRACTOR SHALL REMOVE EXISTING PAGING SPEAKERS (S1) AND REPLACE WITH CEILING TILE OR BLANK COVER PLATE, UNLESS NOTED OTHERWISE.

IN AREAS WITH CONCRETE OR MASONRY WALLS, CONTRACTOR SHALL PROVIDE SURFACE RACEWAY SYSTEM.

IN AREAS WITH EXPOSED CEILINGS, CONTRACTOR SHALL INSTALL ALL CABLING IN CONDUIT. CONTRACTOR TO PERFORM PAINT FINISH AS COORDINATED WITH OWNER.

CONTRACTOR SHALL DEMOLISH ANY UNUSED CABLING BACK TO ITS ORIGIN AND DISPOSE.

CONTRACTOR SHALL REPLACE ALL EXISTING PTT BUTTONS PRESENT IN THE FACILITY WITH A BLANK COVER PLATE. CONTRACTOR SHALL LOCATE, DOCUMENT AND REMEDIATE IN THE SAME METHOD ANY PTT BUTTON NOT EXPLICITLY SHOWN IN THIS DRAWING SET.

CONTRACTOR IS RESPONSIBLE FOR PROVIDING LIFT FOR ALL HIGH CEILING AREAS (FINE ARTS, GYM, ETC.). CONTRACTOR SHALL ALSO BE REQUIRED TO PROVIDE FLOORING PROTECTION.

KEYNOTE LEGEND

(NOT ALL KEYNOTES MAY APPLY.)

01. EXISTING, CONTRACTOR SHALL REPLACE WITH NEW DEVICE AND NEW CABLING. CEILING TILE MAY REMAIN IN PLACE UNLESS DAMAGED.
02. EXISTING, TO REMAIN. CONTRACTOR SHALL INSTALL BRIDGE FROM ANALOG SPEAKER TO IP HEAD END.
03. CONTRACTOR SHALL COMPLETELY REMOVE ALL ABANDONED ANALOG SPEAKER WIRING AND SUPPORTING TERMINAL BLOCKS FROM THE FACILITY. TERMINAL BLOCKS THAT SUPPORT OTHER EXISTING DEVICES SHALL REMAIN.
04. INSTALL PLASTIC 1/2" RACEWAY FOR PATCH CABLE TO TOP OF SURFACE MOUNTED CLOCK BACK BOX. TERMINATE DATA ABOVE CEILING.
05. EXISTING, CONTRACTOR SHALL REMOVE DEVICE, DEMOLISH CABLING BACK TO ITS ORIGIN, AND INSTALL NEW BLANK FACEPLATE.
06. INSTALL DATA IN ADJACENT OVERHEAD CEILING SPACE. PROVIDE 1" SLEEVE THROUGH CMU WALL TO BACK OF CLOCK DISPLAY.
07. SURFACE MOUNTED CONDUIT NEEDED FOR ALL NEW PAGING AND RELATED DEVICES.
08. PROVIDE 1" CONDUIT TO TOP OF SURFACE MOUNTED CLOCK BACK BOX FOR PATCH CABLE. DATA SHALL BE TERMINATED ABOVE CEILING.
09. INSTALL SURFACE MOUNTED RACEWAY FROM DEVICE BACK TO TECH CLOSET LOCATION.
10. CEILING SPEAKER IN CAN MOUNTED TO STRUCTURAL STEEL.
11. THIS IS A PLASTER CEILING, CONDUIT OR PLASTIC RACEWAY WILL NEED TO BE SECURED TO THE CEILING ITSELF.
12. SPEAKERS MOUNTED TO STRUCTURAL STEEL.
13. INSTALL SURFACE RACEWAY FOR ENTIRE PATH FROM TC TO DEVICE.
14. EXISTING SPEAKER BUILT FLUSH IN WALL. DO NOT REMOVE. INSTALL NEW DEVICE ADJACENT TO EXISTING. INSTALL DATA DROP IN ACCESSIBLE CEILING IN ADJACENT SPACE.
15. REMOVE EXISTING HORNS AND LEAVE MOUNTS INTACT, REMOVE EXISTING CABLING. INSTALL NEW DUAL SIDED DEVICE ADJACENT TO FORMER HORN LOCATION. INSTALL DATA IN ADJACENT CEILING SPACE.
16. REFERENCE DIV 27 FOR RACK INFORMATION AND ALLOWANCE REQUIREMENTS. FINAL LOCATIONS TO BE COORDINATED WITH OWNER PRIOR TO INSTALLATION.
17. NOT USED.
18. RECENTLY INSTALLED SPEAKER, REMOVE, PROTECT, AND REDEPLOY WHERE OTHER NEW ANALOG CEILING SPEAKERS ARE NEEDED.
19. J-BOX LARGER THAN 4X4" NEEDED HERE. PROVIDE ADDITIONAL SLACK FOR FUTURE RETERMINATIONS.
20. FIELD CONDITIONS MAY DIFFER FROM WHAT IS SHOWN. COORDINATE EXACT LOCATION WITH OWNER.
21. GYP CEILING. CONTRACTOR SHALL ACCOUNT FOR THREE (3) 24"X24" ACCESS PANEL LOCATIONS IN PRICING. VERIFY PATHWAYS ON SITE.

Description

Date

Revision

Project

SAN ANGELO ISD
PAGING UPGRADE
SAN ANGELO, TEXAS
D-SAN-1003-01




FLOOR PLAN - LAKE VIEW
HS - BUILDING C

Job No. D-SAN-1003-01	Sheet No.
Drawn By: CV	T120
Designed By: CV	
Date: 04/29/2026	

Autosave Docs\\CRUX\\San Angelo ISD Paging System Upgrade\\D-SAN-1003-01 SASD HS Paging Upgrade TECH 02\\HOSTED.rvt

1 FLOOR PLAN - LAKE VIEW HS - BUILDING D
T121 1/8" = 1'-0"

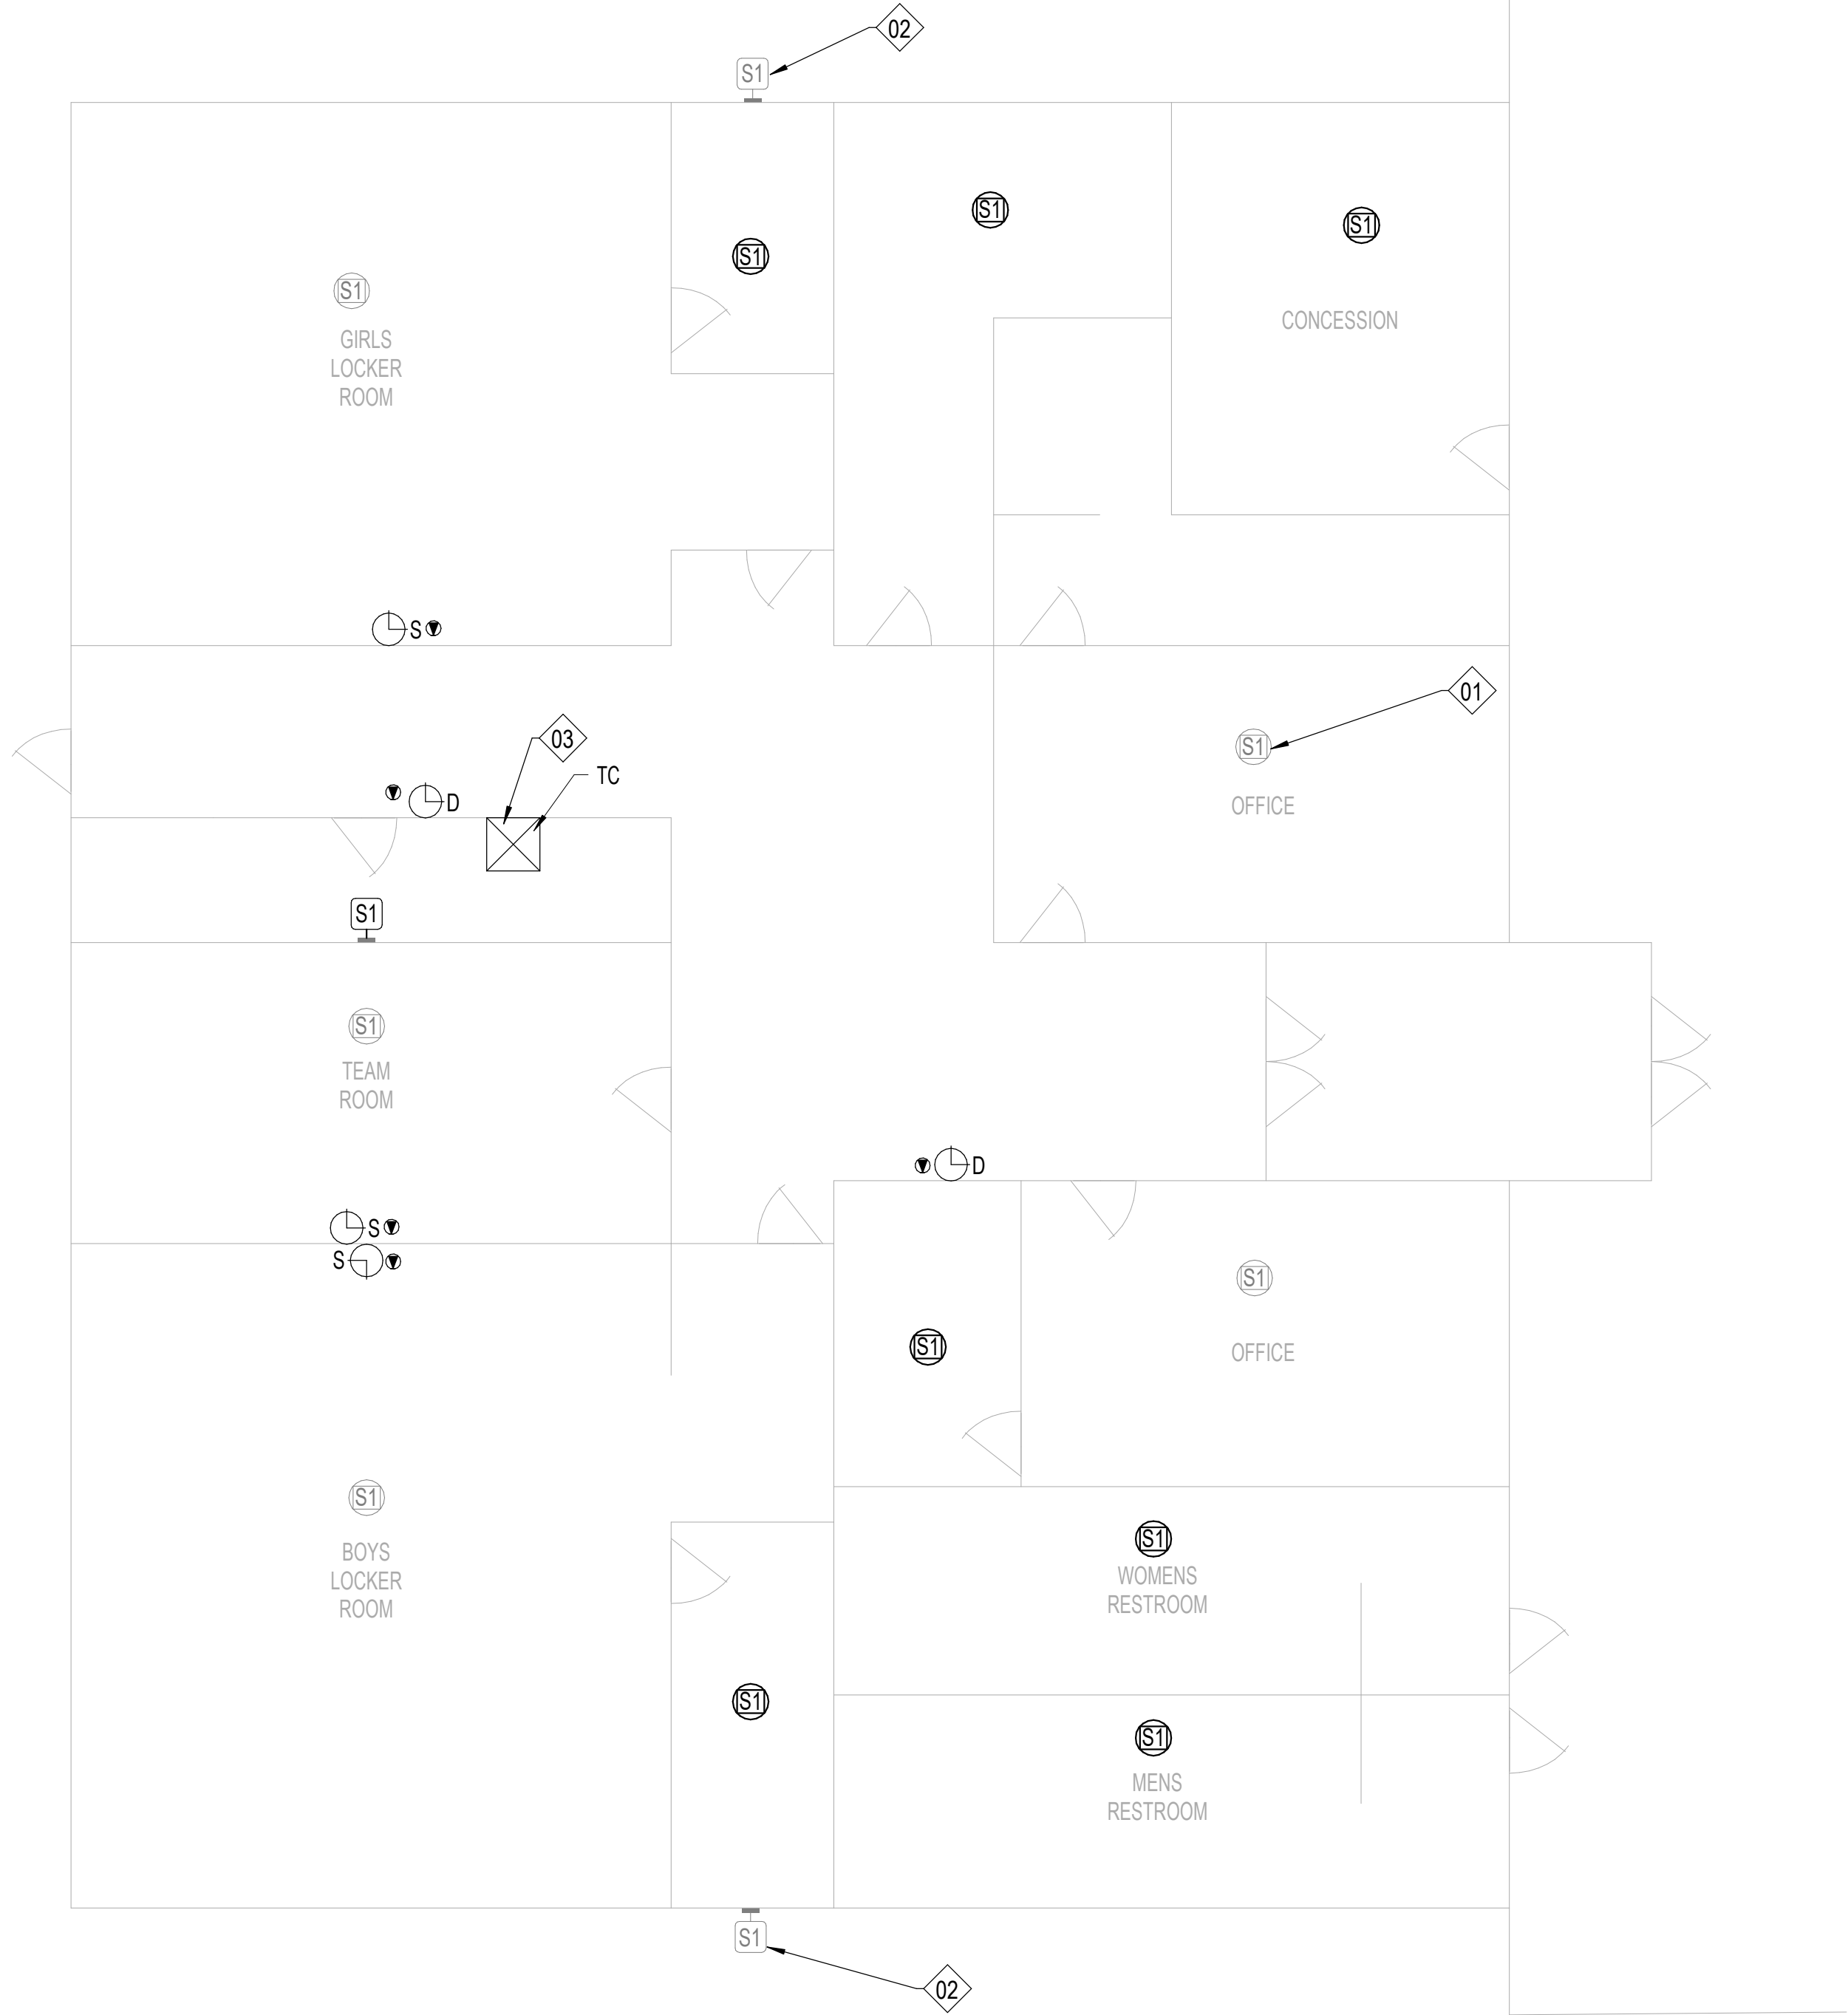

SHEET NOTES:

REFERENCE SHEET TG101 FOR ALL SYMBOLS AND PROJECT SPECIFIC NOTES.

EXISTING PAGING SPEAKERS (S1) ARE SHOWN IN HALF-TONE. CONTRACTOR SHALL REMOVE EXISTING PAGING SPEAKERS (S1) AND REPLACE WITH CEILING TILE OR BLANK COVER PLATE, UNO.

ALL CONDUITS SHALL BE 1" FOR ALL DEVICES UNLESS NOTED OTHERWISE ON THE TECHNOLOGY DRAWINGS.

IN AREAS WITH CONCRETE OR MASONRY WALLS, CONTRACTOR SHALL PROVIDE SURFACE RACEWAY SYSTEM.

IN AREAS WITH EXPOSED CEILINGS, CONTRACTOR SHALL INSTALL ALL CABLING IN CONDUIT. CONTRACTOR TO PERFORM PAINT FINISH AS COORDINATED WITH OWNER.

CONTRACTOR SHALL DEMOLISH ANY UNUSED CABLING BACK TO ITS ORIGIN AND DISPOSE.

CONTRACTOR SHALL REPLACE ALL EXISTING PTT BUTTONS PRESENT IN THE FACILITY WITH A BLANK COVER PLATE. CONTRACTOR SHALL LOCATE, DOCUMENT AND REMEDIATE IN THE SAME METHOD ANY PTT BUTTON NOT EXPLICITLY SHOWN IN THIS DRAWING SET.

CONTRACTOR IS RESPONSIBLE FOR PROVIDING LIFT FOR ALL HIGH CEILING AREAS (FINE ARTS, GYM, ETC.). CONTRACTOR SHALL ALSO BE REQUIRED TO PROVIDE FLOORING PROTECTION.

KEYNOTE LEGEND

(NOT ALL KEYNOTES MAY APPLY.)

01. EXISTING, CONTRACTOR SHALL REPLACE WITH NEW DEVICE AND NEW CABLING. CEILING TILE MAY REMAIN IN PLACE UNLESS DAMAGED.
02. EXISTING, TO REMAIN. CONTRACTOR SHALL INSTALL BRIDGE FROM ANALOG SPEAKER TO IP HEAD END.
03. CONTRACTOR SHALL COMPLETELY REMOVE ALL ABANDONED ANALOG SPEAKER WIRING AND SUPPORTING TERMINAL BLOCKS FROM THE FACILITY. TERMINAL BLOCKS THAT SUPPORT OTHER EXISTING DEVICES SHALL REMAIN.
04. INSTALL PLASTIC 1/2" RACEWAY FOR PATCH CABLE TO TOP OF SURFACE MOUNTED CLOCK BACK BOX. TERMINATE DATA ABOVE CEILING.
05. EXISTING, CONTRACTOR SHALL REMOVE DEVICE, DEMOLISH CABLING BACK TO ITS ORIGIN, AND INSTALL NEW BLANK FACEPLATE.
06. INSTALL DATA IN ADJACENT OVERHEAD CEILING SPACE. PROVIDE 1" SLEEVE THROUGH CMU WALL TO BACK OF CLOCK DISPLAY.
07. SURFACE MOUNTED CONDUIT NEEDED FOR ALL NEW PAGING AND RELATED DEVICES.
08. PROVIDE 1" CONDUIT TO TOP OF SURFACE MOUNTED CLOCK BACK BOX FOR PATCH CABLE. DATA SHALL BE TERMINATED ABOVE CEILING.
09. INSTALL SURFACE MOUNTED RACEWAY FROM DEVICE BACK TO TECH CLOSET LOCATION.
10. CEILING SPEAKER IN CAN MOUNTED TO STRUCTURAL STEEL.
11. THIS IS A PLASTER CEILING, CONDUIT OR PLASTIC RACEWAY WILL NEED TO BE SECURED TO THE CEILING ITSELF.
12. SPEAKERS MOUNTED TO STRUCTURAL STEEL.
13. INSTALL SURFACE RACEWAY FOR ENTIRE PATH FROM TC TO DEVICE.
14. EXISTING SPEAKER BUILT FLUSH IN WALL. DO NOT REMOVE. INSTALL NEW DEVICE ADJACENT TO EXISTING. INSTALL DATA DROP IN ACCESSIBLE CEILING IN ADJACENT SPACE.
15. REMOVE EXISTING HORNS AND LEAVE MOUNTS INTACT, REMOVE EXISTING CABLING. INSTALL NEW DUAL SIDED DEVICE ADJACENT TO FORMER HORN LOCATION. INSTALL DATA IN ADJACENT CEILING SPACE.
16. REFERENCE DIV 27 FOR RACK INFORMATION AND ALLOWANCE REQUIREMENTS. FINAL LOCATIONS TO BE COORDINATED WITH OWNER PRIOR TO INSTALLATION.
17. NOT USED.
18. RECENTLY INSTALLED SPEAKER, REMOVE, PROTECT, AND REDEPLOY WHERE OTHER NEW ANALOG CEILING SPEAKERS ARE NEEDED.
19. J-BOX LARGER THAN 4X4" NEEDED HERE. PROVIDE ADDITIONAL SLACK FOR FUTURE RETERMINATIONS.
20. FIELD CONDITIONS MAY DIFFER FROM WHAT IS SHOWN. COORDINATE EXACT LOCATION WITH OWNER.
21. GYP CEILING. CONTRACTOR SHALL ACCOUNT FOR THREE (3) 24"x24" ACCESS PANEL LOCATIONS IN PRICING. VERIFY PATHWAYS ON SITE.

Description

Date

Revision

Project

SAN ANGELO ISD
PAGING UPGRADE
SAN ANGELO, TEXAS
D-SAN-1003-01



FLOOR PLAN - LAKE VIEW
HS - BUILDING D

Job No.
D-SAN-1003-01
Drawn By:
CV
Designed By:
CV
Date:
04/29/2026
Sheet No.
T121

SHEET NOTES:

REFERENCE SHEET TG101 FOR ALL SYMBOLS AND PROJECT SPECIFIC NOTES.

EXISTING PAGING SPEAKERS (S1) ARE SHOWN IN HALFTONE. CONTRACTOR SHALL REMOVE EXISTING PAGING SPEAKERS (S1) AND REPLACE WITH CEILING TILE OR BLANK COVER PLATE, U.N.O.

ALL CONDUITS SHALL BE 1" FOR ALL DEVICES UNLESS NOTED OTHERWISE ON THE TECHNOLOGY DRAWINGS.

IN AREAS WITH CONCRETE OR MASONRY WALLS, CONTRACTOR SHALL PROVIDE SURFACE RACEWAY SYSTEM.

IN AREAS WITH EXPOSED CEILINGS, CONTRACTOR SHALL INSTALL ALL CABLING IN CONDUIT. CONTRACTOR TO PERFORM PAINT FINISH AS COORDINATED WITH OWNER.

CONTRACTOR SHALL DEMOLISH ANY UNUSED CABLING BACK TO ITS ORIGIN AND DISPOSE.

CONTRACTOR SHALL REPLACE ALL EXISTING PTT BUTTONS PRESENT IN THE FACILITY WITH A BLANK COVER PLATE. CONTRACTOR SHALL LOCATE, DOCUMENT AND REMEDIATE IN THE SAME METHOD ANY PTT BUTTON NOT EXPLICITLY SHOWN IN THIS DRAWING SET.

CONTRACTOR IS RESPONSIBLE FOR PROVIDING LIFT FOR ALL HIGH CEILING AREAS (FINE ARTS, GYMS, ETC.). CONTRACTOR SHALL ALSO BE REQUIRED TO PROVIDE FLOORING PROTECTION.

KEYNOTE LEGEND

(NOT ALL KEYNOTES MAY APPLY)

01. EXISTING. CONTRACTOR SHALL REPLACE WITH NEW DEVICE AND NEW CABLING. CEILING TILE MAY REMAIN IN PLACE UNLESS DAMAGED.

02. EXISTING. TO REMAIN. CONTRACTOR SHALL INSTALL BRIDGE FROM ANALOG SPEAKER TO IP HEAD END.

03. CONTRACTOR SHALL COMPLETELY REMOVE ALL ABANDONED ANALOG SPEAKER WIRING AND SUPPORTING TERMINAL BLOCKS FROM THE FACILITY. TERMINAL BLOCKS THAT SUPPORT OTHER EXISTING DEVICES SHALL REMAIN.

04. INSTALL PLASTIC 1/2" RACEWAY FOR PATCH CABLE TO TOP OF SURFACE MOUNTED CLOCK BACK BOX. TERMINATE DATA ABOVE CEILING.

05. EXISTING; CONTRACTOR SHALL REMOVE DEVICE. DEMOLISH CABLING BACK TO ITS ORIGIN, AND INSTALL NEW BLANK FACEPLATE.

06. INSTALL DATA IN ADJACENT OVERHEAD CEILING SPACE. PROVIDE 1" SLEEVE THROUGH CMU WALL TO BACK OF CLOCK DISPLAY.

07. SURFACE MOUNTED CONDUIT NEEDED FOR ALL NEW PAGING AND RELATED DEVICES.

08. PROVIDE 1" CONDUIT TO TOP OF SURFACE MOUNTED CLOCK BACK BOX FOR PATCH CABLE. DATA SHALL BE TERMINATED ABOVE CEILING.

09. INSTALL SURFACE MOUNTED RACEWAY FROM DEVICE BACK TO TECH CLOSET LOCATION.

10. CEILING SPEAKER IN CAN MOUNTED TO STRUCTURAL STEEL.

11. THIS IS A PLASTER CEILING. CONDUIT OR PLASTIC RACEWAY WILL NEED TO BE SECURED TO THE CEILING ITSELF.

KEYNOTE LEGEND

(NOT ALL KEYNOTES MAY APPLY)

12. SPEAKERS MOUNTED TO STRUCTURAL STEEL.

13. INSTALL SURFACE RACEWAY FOR ENTIRE PATH FROM TC TO DEVICE.

14. EXISTING SPEAKER BUILT FLUSH IN WALL. DO NOT REMOVE. INSTALL NEW DEVICE ADJACENT TO EXISTING. INSTALL DATA DROP IN ACCESSIBLE CEILING IN ADJACENT SPACE.

15. REMOVE EXISTING HORNS AND LEAVE MOUNTS INTACT. REMOVE EXISTING CABLING. INSTALL NEW DUAL SIDED DEVICE ADJACENT TO FORMER HORN LOCATION. INSTALL DATA IN ADJACENT CEILING SPACE.

16. REFERENCE DIV 27 FOR RACK INFORMATION AND ALLOWANCE REQUIREMENTS. FINAL LOCATIONS TO BE COORDINATED WITH OWNER PRIOR TO INSTALLATION.


17. NOT USED

18. RECENTLY INSTALLED SPEAKER. REMOVE, PROTECT, AND REDEPLOY WHERE OTHER NEW ANALOG CEILING SPEAKERS ARE NEEDED.

19. J-BOX LARGER THAN 4X4" NEEDED HERE. PROVIDE ADDITIONAL SLACK FOR FUTURE RETERMINATIONS.

20. FIELD CONDITIONS MAY DIFFER FROM WHAT IS SHOWN. COORDINATE EXACT LOCATION WITH OWNER.

21. GYP CEILING. CONTRACTOR SHALL ACCOUNT FOR THREE (3) 24"X24" ACCESS PANEL LOCATIONS IN PRICING. VERIFY PATHWAYS ON SITE.

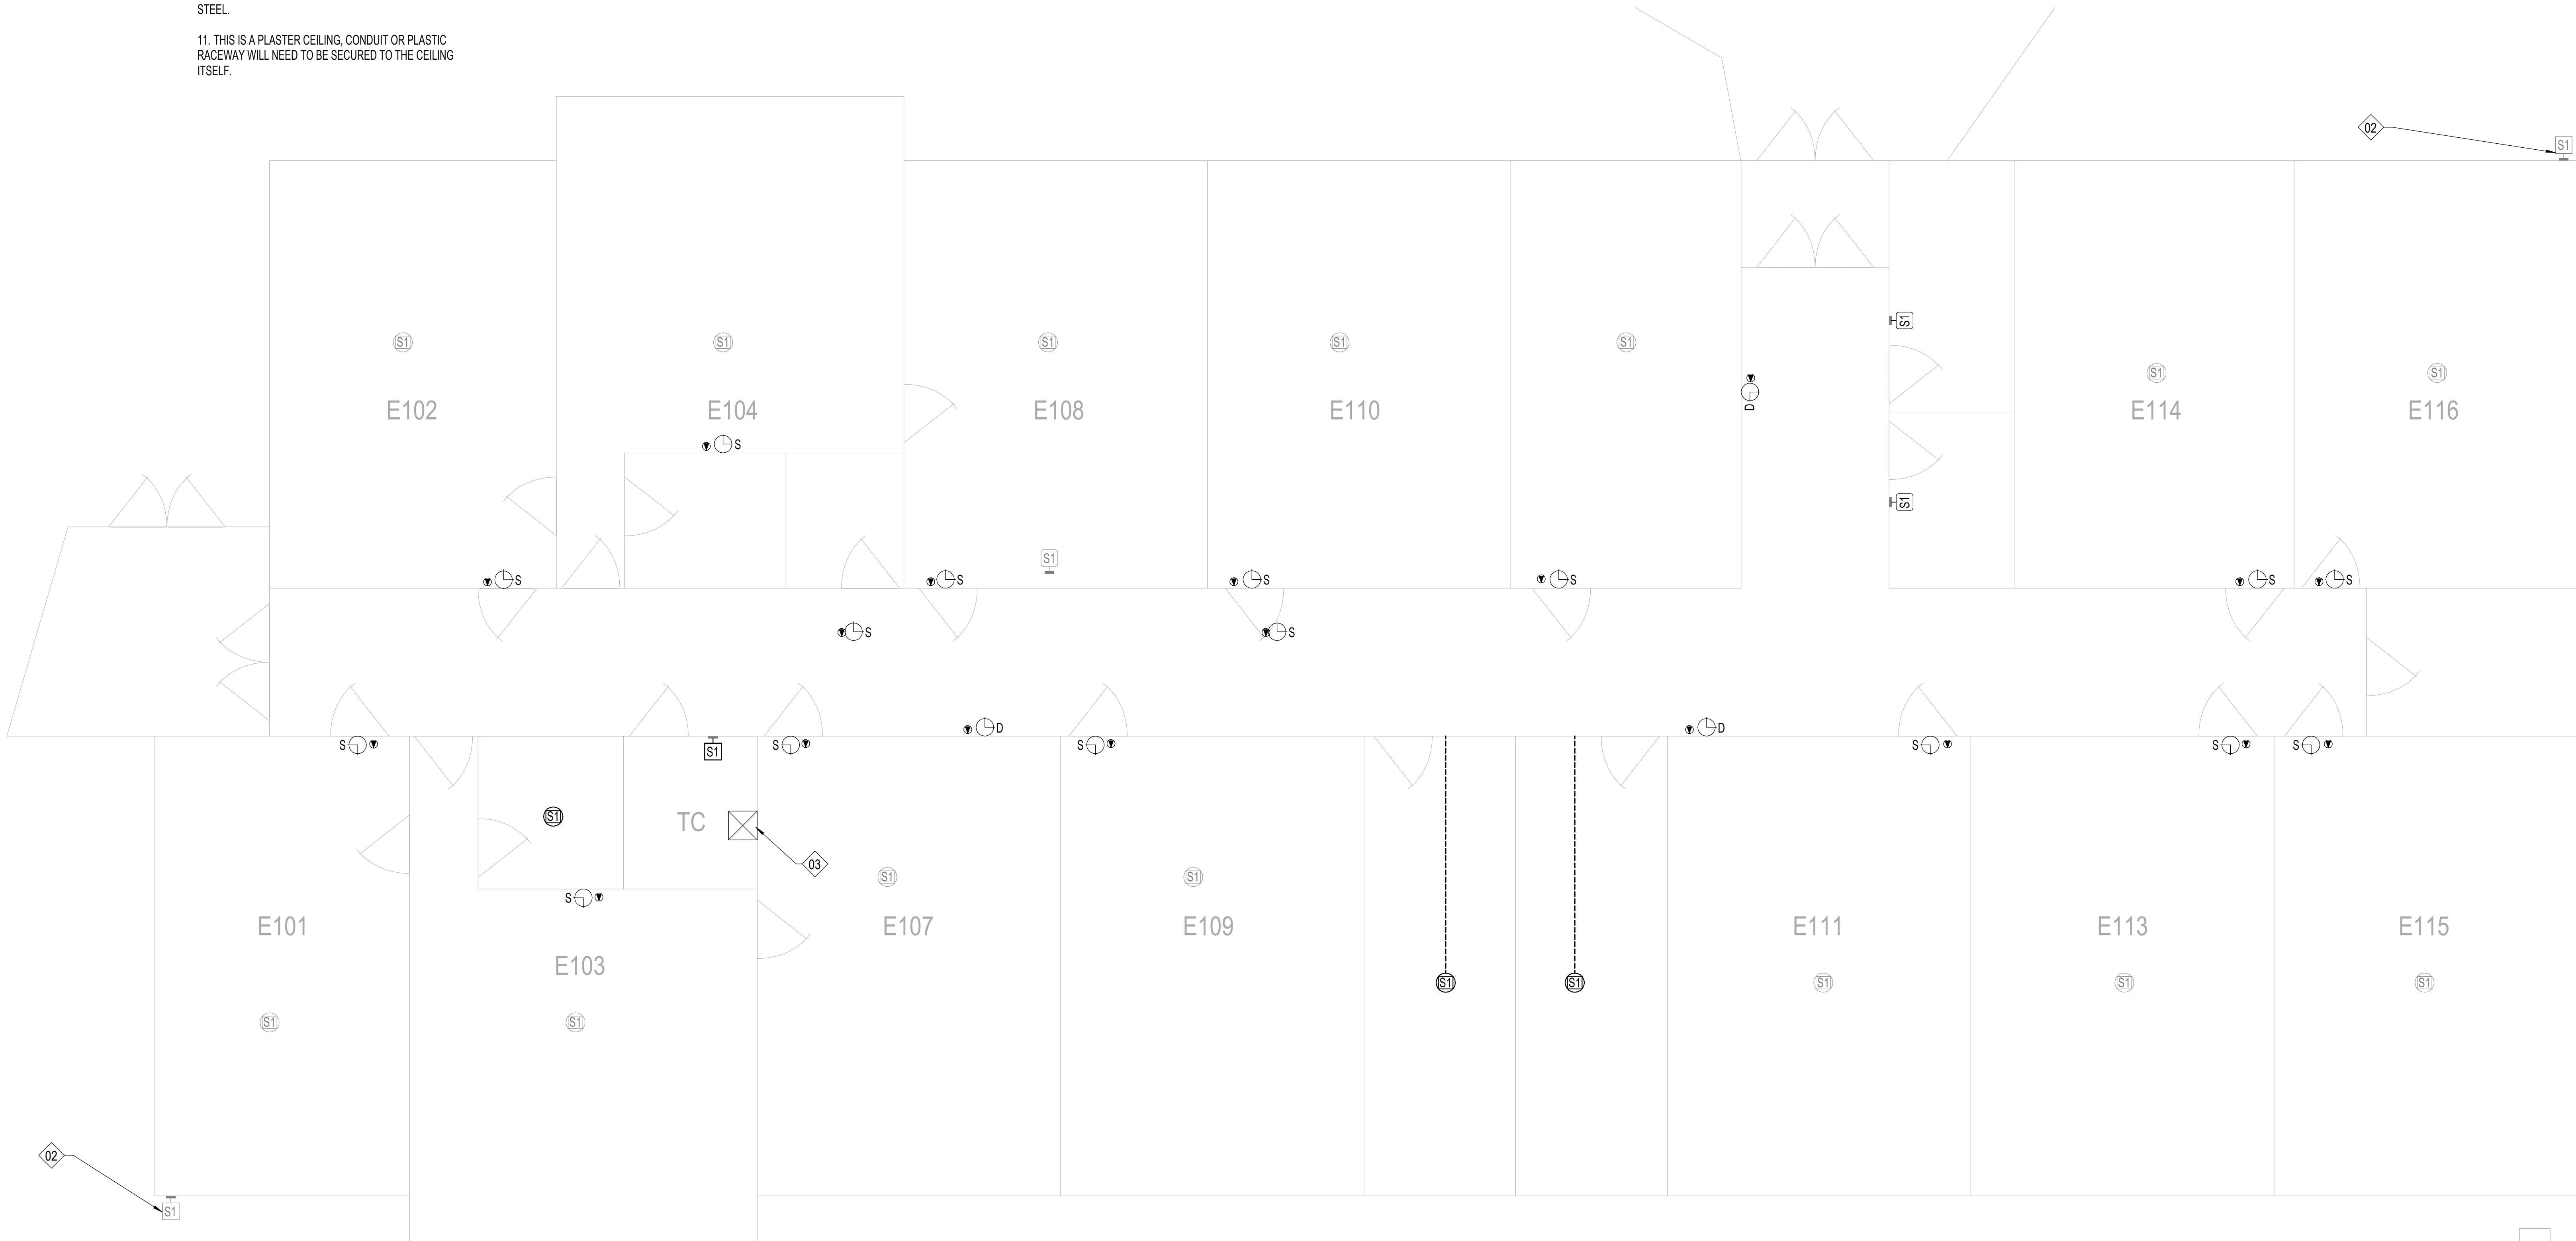

1 FLOOR PLAN - LAKE VIEW HS - BUILDING G
T122 1/8" = 1'-0"



Description

Date:

Revision:

Project:


SAN ANGELO ISD
PAGING UPGRADE
SAN ANGELO, TEXAS
D-SAN-1003-01



FLOOR PLAN - LAKE VIEW
HS - BUILDING G

Job No.
D-SAN-1003-01
Drawn By:
CV
Designed By:
CV
Date:
04/29/2026
Sheet No.
T122

Autodesk Docs\\CRUX-San Angelo ISD Paging System Upgrade\\D-SAN-1003-01 SANSD-103_Paging Upgrade_Tech_02\\HOSTED.rvt

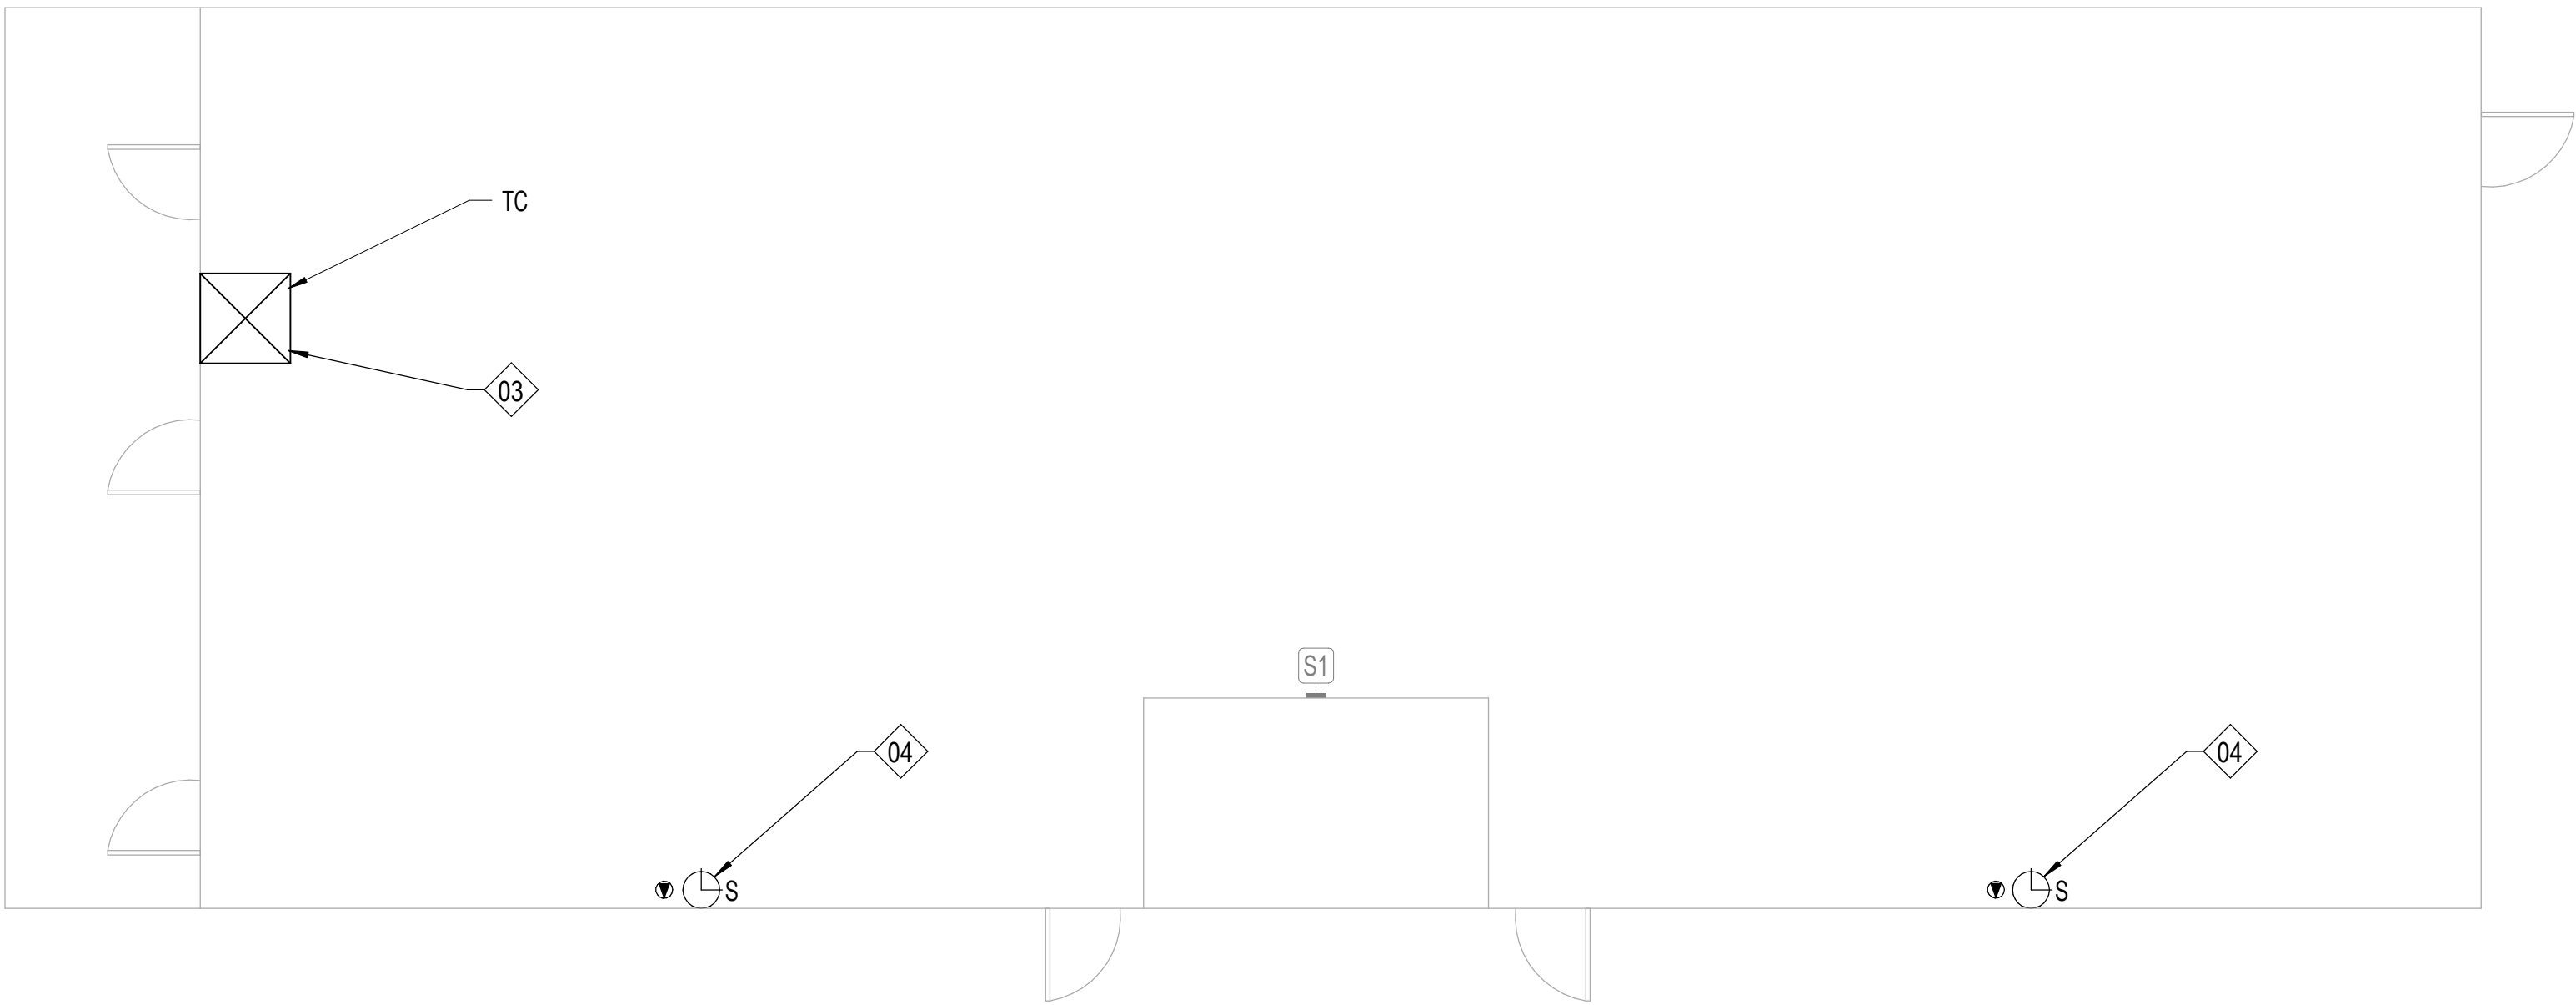

1 FLOOR PLAN - LAKE VIEW HS - PORTABLE (SNACK SHACK)
1103 NTS

SHEET NOTES:

REFERENCE SHEET TG101 FOR ALL SYMBOLS AND PROJECT SPECIFIC NOTES.

EXISTING PAGING SPEAKERS (S1) ARE SHOWN IN HALF-TONE. CONTRACTOR SHALL REMOVE EXISTING PAGING SPEAKERS (S1) AND REPLACE WITH CEILING TILE OR BLANK COVER PLATE, UNO.

ALL CONDUITS SHALL BE 1" FOR ALL DEVICES UNLESS NOTED OTHERWISE ON THE TECHNOLOGY DRAWINGS.

IN AREAS WITH CONCRETE OR MASONRY WALLS, CONTRACTOR SHALL PROVIDE SURFACE RACEWAY SYSTEM.

IN AREAS WITH EXPOSED CEILINGS, CONTRACTOR SHALL INSTALL ALL CABLING IN CONDUIT. CONTRACTOR TO PERFORM PAINT FINISH AS COORDINATED WITH OWNER.

CONTRACTOR SHALL DEMOLISH ANY UNUSED CABLING BACK TO ITS ORIGIN AND DISPOSE.

CONTRACTOR SHALL REPLACE ALL EXISTING PTT BUTTONS PRESENT IN THE FACILITY WITH A BLANK COVER PLATE. CONTRACTOR SHALL LOCATE, DOCUMENT AND REMEDIATE IN THE SAME METHOD ANY PTT BUTTON NOT EXPLICITLY SHOWN IN THIS DRAWING SET.

CONTRACTOR IS RESPONSIBLE FOR PROVIDING LIFT FOR ALL HIGH CEILING AREAS (FINE ARTS, GYM, ETC.). CONTRACTOR SHALL ALSO BE REQUIRED TO PROVIDE FLOORING PROTECTION.

KEYNOTE LEGEND

(NOT ALL KEYNOTES MAY APPLY.)

01. EXISTING, CONTRACTOR SHALL REPLACE WITH NEW DEVICE AND NEW CABLING. CEILING TILE MAY REMAIN IN PLACE UNLESS DAMAGED.

02. EXISTING, TO REMAIN. CONTRACTOR SHALL INSTALL BRIDGE FROM ANALOG SPEAKER TO IP HEAD END.

03. CONTRACTOR SHALL COMPLETELY REMOVE ALL ABANDONED ANALOG SPEAKER WIRING AND SUPPORTING TERMINAL BLOCKS FROM THE FACILITY. TERMINAL BLOCKS THAT SUPPORT OTHER EXISTING DEVICES SHALL REMAIN.

04. INSTALL PLASTIC 1/2" RACEWAY FOR PATCH CABLE TO TOP OF SURFACE MOUNTED CLOCK BACK BOX. TERMINATE DATA ABOVE CEILING.

05. EXISTING, CONTRACTOR SHALL REMOVE DEVICE, DEMOLISH CABLING BACK TO ITS ORIGIN, AND INSTALL NEW BLANK FACEPLATE.

06. INSTALL DATA IN ADJACENT OVERHEAD CEILING SPACE. PROVIDE 1" SLEEVE THROUGH CMU WALL TO BACK OF CLOCK DISPLAY.

07. SURFACE MOUNTED CONDUIT NEEDED FOR ALL NEW PAGING AND RELATED DEVICES.

08. PROVIDE 1" CONDUIT TO TOP OF SURFACE MOUNTED CLOCK BACK BOX FOR PATCH CABLE. DATA SHALL BE TERMINATED ABOVE CEILING.

09. INSTALL SURFACE MOUNTED RACEWAY FROM DEVICE BACK TO TECH CLOSET LOCATION.

10. CEILING SPEAKER IN CAN MOUNTED TO STRUCTURAL STEEL.

11. THIS IS A PLASTER CEILING, CONDUIT OR PLASTIC RACEWAY WILL NEED TO BE SECURED TO THE CEILING ITSELF.

12. SPEAKERS MOUNTED TO STRUCTURAL STEEL.

13. INSTALL SURFACE RACEWAY FOR ENTIRE PATH FROM TC TO DEVICE.

14. EXISTING SPEAKER BUILT FLUSH IN WALL. DO NOT REMOVE. INSTALL NEW DEVICE ADJACENT TO EXISTING. INSTALL DATA DROP IN ACCESSIBLE CEILING IN ADJACENT SPACE.

15. REMOVE EXISTING HORNS AND LEAVE MOUNTS INTACT, REMOVE EXISTING CABLING. INSTALL NEW DUAL SIDED DEVICE ADJACENT TO FORMER HORN LOCATION. INSTALL DATA IN ADJACENT CEILING SPACE.

16. REFERENCE DIV 27 FOR RACK INFORMATION AND ALLOWANCE REQUIREMENTS. FINAL LOCATIONS TO BE COORDINATED WITH OWNER PRIOR TO INSTALLATION.


17. NOT USED.

18. RECENTLY INSTALLED SPEAKER, REMOVE, PROTECT, AND REDEPLOY WHERE OTHER NEW ANALOG CEILING SPEAKERS ARE NEEDED.

19. J-BOX LARGER THAN 4X4" NEEDED HERE. PROVIDE ADDITIONAL SLACK FOR FUTURE RETERMINATIONS.

20. FIELD CONDITIONS MAY DIFFER FROM WHAT IS SHOWN. COORDINATE EXACT LOCATION WITH OWNER.

21. GYP CEILING. CONTRACTOR SHALL ACCOUNT FOR THREE (3) 24"X24" ACCESS PANEL LOCATIONS IN PRICING. VERIFY PATHWAYS ON SITE.

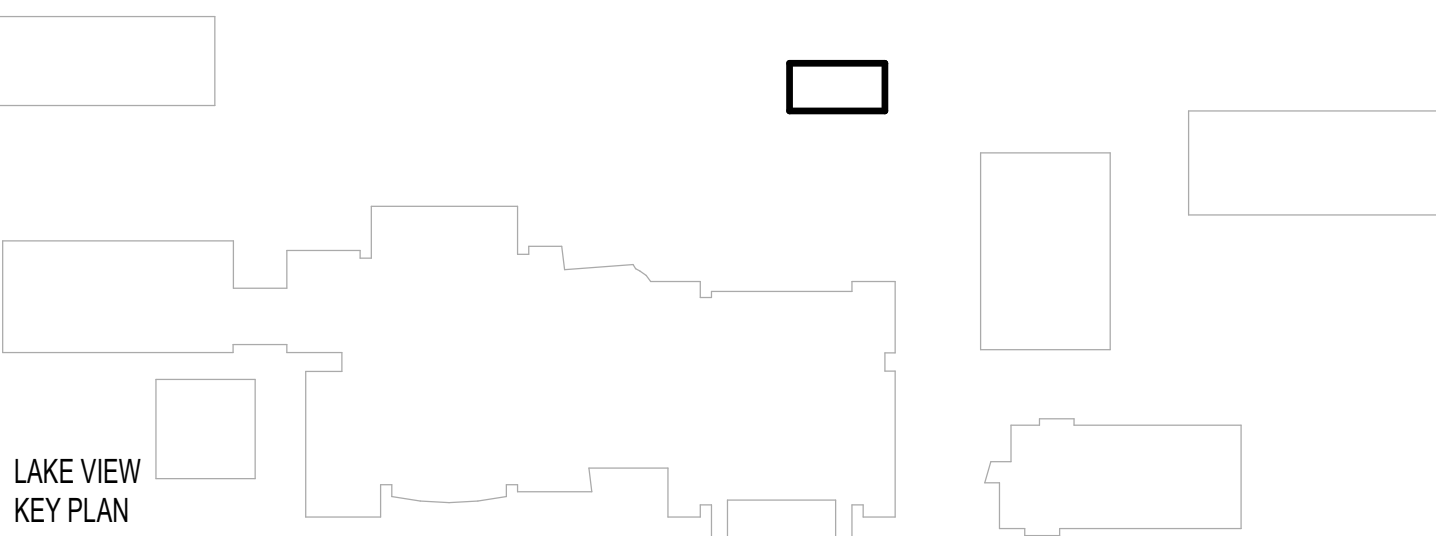

Description

Date

Revision

Project

SAN ANGELO ISD
PAGING UPGRADE
SAN ANGELO, TEXAS
D-SAN-1003-01




FLOOR PLAN - LAKE VIEW
HS - PORTABLES (SNACK
SHACK)

Job No. D-SAN-1003-01	Sheet No.
Drawn By: CV	T123
Designed By: CV	
Date: 04/29/2026	

21. GYP CEILING. CONTRACTOR SHALL ACCOUNT FOR THREE (3) 24"X24" ACCESS PANEL LOCATIONS IN PRICING. VERIFY PATHWAYS ON SITE.

T124

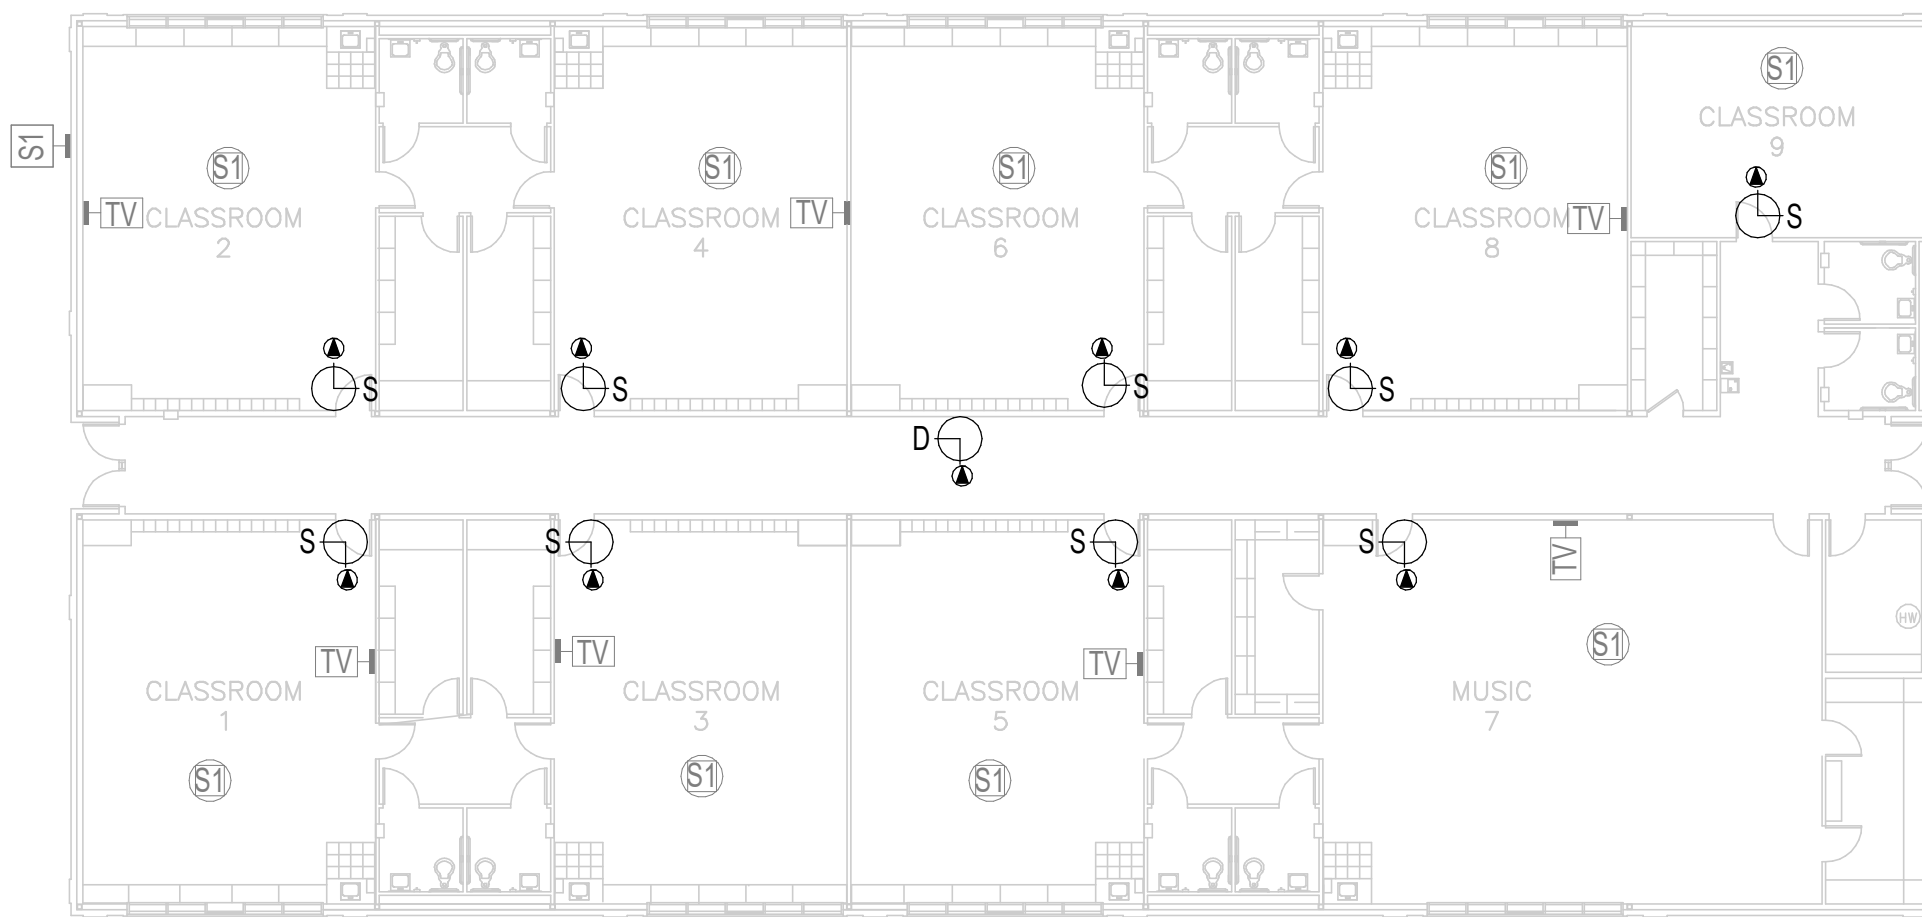



21. GYP CEILING. CONTRACTOR SHALL ACCOUNT FOR THREE (3) 24"X24" ACCESS PANEL LOCATIONS IN PRICING. VERIFY PATHWAYS ON SITE.

T125

Autodesk Docs: CRUX-San Angelo ISD Paging System Upgrade\B-SAN-1003-01 SANSD ISD Paging Upgrade, TECH, 02\HOSTED.rvt



1 FLOOR PLAN - BRADFORD ES
T108 1" = 10'-0"

SHEET NOTES:

REFERENCE SHEET TG101 FOR ALL SYMBOLS AND PROJECT SPECIFIC NOTES.

EXISTING PAGING SPEAKERS (S1) ARE SHOWN IN HALF-TONE. CONTRACTOR SHALL REMOVE EXISTING PAGING SPEAKERS (S1) AND REPLACE WITH CEILING TILE OR BLANK COVER PLATE, UNO.

ALL CONDUITS SHALL BE 1" FOR ALL DEVICES UNLESS NOTED OTHERWISE ON THE TECHNOLOGY DRAWINGS.

IN AREAS WITH CONCRETE OR MASONRY WALLS, CONTRACTOR SHALL PROVIDE SURFACE RACEWAY SYSTEM.

IN AREAS WITH EXPOSED CEILINGS, CONTRACTOR SHALL INSTALL ALL CABLING IN CONDUIT. CONTRACTOR TO PERFORM PAINT FINISH AS COORDINATED WITH OWNER.

CONTRACTOR SHALL DEMOLISH ANY UNUSED CABLING BACK TO ITS ORIGIN AND DISPOSE.

CONTRACTOR SHALL REPLACE ALL EXISTING PTT BUTTONS PRESENT IN THE FACILITY WITH A BLANK COVER PLATE. CONTRACTOR SHALL LOCATE, DOCUMENT AND REMEDIATE IN THE SAME METHOD ANY PTT BUTTON NOT EXPLICITLY SHOWN IN THIS DRAWING SET.

CONTRACTOR IS RESPONSIBLE FOR PROVIDING LIFT FOR ALL HIGH CEILING AREAS (FINE ARTS, GYM, ETC.). CONTRACTOR SHALL ALSO BE REQUIRED TO PROVIDE FLOORING PROTECTION.

KEYNOTE LEGEND

(NOT ALL KEYNOTES MAY APPLY.)

01. EXISTING, CONTRACTOR SHALL REPLACE WITH NEW DEVICE AND NEW CABLING. CEILING TILE MAY REMAIN IN PLACE UNLESS DAMAGED.

02. EXISTING, TO REMAIN. CONTRACTOR SHALL INSTALL BRIDGE FROM ANALOG SPEAKER TO IP HEAD END.

03. CONTRACTOR SHALL COMPLETELY REMOVE ALL ABANDONED ANALOG SPEAKER WIRING AND SUPPORTING TERMINAL BLOCKS FROM THE FACILITY. TERMINAL BLOCKS THAT SUPPORT OTHER EXISTING DEVICES SHALL REMAIN.

04. INSTALL PLASTIC 1/2" RACEWAY FOR PATCH CABLE TO TOP OF SURFACE MOUNTED CLOCK BACK BOX. TERMINATE DATA ABOVE CEILING.

05. EXISTING, CONTRACTOR SHALL REMOVE DEVICE, DEMOLISH CABLING BACK TO ITS ORIGIN, AND INSTALL NEW BLANK FACEPLATE.

06. INSTALL DATA IN ADJACENT OVERHEAD CEILING SPACE. PROVIDE 1" SLEEVE THROUGH CMU WALL TO BACK OF CLOCK DISPLAY.

07. SURFACE MOUNTED CONDUIT NEEDED FOR ALL NEW PAGING AND RELATED DEVICES.

08. PROVIDE 1" CONDUIT TO TOP OF SURFACE MOUNTED CLOCK BACK BOX FOR PATCH CABLE. DATA SHALL BE TERMINATED ABOVE CEILING.

09. INSTALL SURFACE MOUNTED RACEWAY FROM DEVICE BACK TO TECH CLOSET LOCATION.

10. CEILING SPEAKER IN CAN MOUNTED TO STRUCTURAL STEEL.

11. THIS IS A PLASTER CEILING, CONDUIT OR PLASTIC RACEWAY WILL NEED TO BE SECURED TO THE CEILING ITSELF.

12. SPEAKERS MOUNTED TO STRUCTURAL STEEL.

13. INSTALL SURFACE RACEWAY FOR ENTIRE PATH FROM TC TO DEVICE.

14. EXISTING SPEAKER BUILT FLUSH IN WALL. DO NOT REMOVE. INSTALL NEW DEVICE ADJACENT TO EXISTING. INSTALL DATA DROP IN ACCESSIBLE CEILING IN ADJACENT SPACE.

15. REMOVE EXISTING HORNS AND LEAVE MOUNTS INTACT. REMOVE EXISTING CABLING. INSTALL NEW DUAL SIDED DEVICE ADJACENT TO FORMER HORN LOCATION. INSTALL DATA IN ADJACENT CEILING SPACE.

16. REFERENCE DIV 27 FOR RACK INFORMATION AND ALLOWANCE REQUIREMENTS. FINAL LOCATIONS TO BE COORDINATED WITH OWNER PRIOR TO INSTALLATION.

17. NOT USED.

18. RECENTLY INSTALLED SPEAKER. REMOVE, PROTECT, AND REDEPLOY WHERE OTHER NEW ANALOG CEILING SPEAKERS ARE NEEDED.

19. J-BOX LARGER THAN 4X4" NEEDED HERE. PROVIDE ADDITIONAL SLACK FOR FUTURE RETERMINATIONS.

20. FIELD CONDITIONS MAY DIFFER FROM WHAT IS SHOWN. COORDINATE EXACT LOCATION WITH OWNER.

21. GYP CEILING. CONTRACTOR SHALL ACCOUNT FOR THREE (3) 24"x24" ACCESS PANEL LOCATIONS IN PRICING. VERIFY PATHWAYS ON SITE.

Description

Addendum 01

Date: 05/18/25

Revision: 1

SAN ANGELO ISD
PAGING UPGRADE
SAN ANGELO, TEXAS
D-SAN-1003-01

Project:



CRUX
TECHNOLOGY • SECURITY SOLUTIONS
800.665.6440
www.cruxsolutions.com

FLOOR PLAN - BRADFORD ES

Job No.
D-SAN-1003-01

Drawn By:
CV

Designed By:
CV

Date:
04/29/2025

Sheet No.

T126

KEYNOTE LEGEND

(NOT ALL KEYNOTES MAY APPLY)

01. EXISTING. CONTRACTOR SHALL REPLACE WITH NEW DEVICE AND NEW CABLING. CEILING TILE MAY REMAIN IN PLACE UNLESS DAMAGED.
02. EXISTING. TO REMAIN. CONTRACTOR SHALL INSTALL BRIDGE FROM ANALOG SPEAKER TO IP HEAD END.
03. CONTRACTOR SHALL COMPLETELY REMOVE ALL ABANDONED ANALOG SPEAKER WIRING AND SUPPORTING TERMINAL BLOCKS FROM THE FACILITY. TERMINAL BLOCKS THAT SUPPORT OTHER EXISTING DEVICES SHALL REMAIN.
04. INSTALL PLASTIC 1/2" RACEWAY FOR PATCH CABLE TO TOP OF SURFACE MOUNTED CLOCK BACK BOX. TERMINATE DATA ABOVE CEILING.
05. EXISTING. CONTRACTOR SHALL REMOVE DEVICE. DEMOLISH CABLING BACK TO ITS ORIGIN, AND INSTALL NEW BLANK FACEPLATE.
06. INSTALL DATA IN ADJACENT OVERHEAD CEILING SPACE. PROVIDE 1" SLEEVE THROUGH CMU WALL TO BACK OF CLOCK DISPLAY.
07. SURFACE MOUNTED CONDUIT NEEDED FOR ALL NEW PAGING AND RELATED DEVICES.
08. PROVIDE 1" CONDUIT TO TOP OF SURFACE MOUNTED CLOCK BACK BOX FOR PATCH CABLE. DATA SHALL BE TERMINATED ABOVE CEILING.
09. INSTALL SURFACE MOUNTED RACEWAY FROM DEVICE BACK TO TECH CLOSET LOCATION.
10. CEILING SPEAKER IN CAN MOUNTED TO STRUCTURAL STEEL.
11. THIS IS A PLASTER CEILING. CONDUIT OR PLASTIC RACEWAY WILL NEED TO BE SECURED TO THE CEILING ITSELF.
12. SPEAKERS MOUNTED TO STRUCTURAL STEEL.
13. INSTALL SURFACE RACEWAY FOR ENTIRE PATH FROM TC TO DEVICE.
14. EXISTING SPEAKER BUILT FLUSH IN WALL. DO NOT REMOVE. INSTALL NEW DEVICE ADJACENT TO EXISTING. INSTALL DATA DROP IN ACCESSIBLE CEILING IN ADJACENT SPACE.
15. REMOVE EXISTING HORNS AND LEAVE MOUNTS INTACT. REMOVE EXISTING CABLING. INSTALL NEW DUAL SIDED DEVICE ADJACENT TO FORMER HORN LOCATION. INSTALL DATA IN ADJACENT CEILING SPACE.
16. REFERENCE DIV 27 FOR RACK INFORMATION AND ALLOWANCE REQUIREMENTS. FINAL LOCATIONS TO BE COORDINATED WITH OWNER PRIOR TO INSTALLATION.
17. NOT USED.
18. RECENTLY INSTALLED SPEAKER. REMOVE, PROTECT, AND REDEPLOY WHERE OTHER NEW ANALOG CEILING SPEAKERS ARE NEEDED.
19. J-BOX LARGER THAN 4X4" NEEDED HERE. PROVIDE ADDITIONAL SLACK FOR FUTURE RETERMINATIONS.
20. FIELD CONDITIONS MAY DIFFER FROM WHAT IS SHOWN. COORDINATE EXACT LOCATION WITH OWNER.
21. GYP CEILING. CONTRACTOR SHALL ACCOUNT FOR THREE (3) 24"X24" ACCESS PANEL LOCATIONS IN PRICING. VERIFY PATHWAYS ON SITE.

SHEET NOTES:

REFERENCE SHEET TG101 FOR ALL SYMBOLS AND PROJECT SPECIFIC NOTES.

EXISTING PAGING SPEAKERS (S1) ARE SHOWN IN HALFTONE. CONTRACTOR SHALL REMOVE EXISTING PAGING SPEAKERS (S1) AND REPLACE WITH CEILING TILE OR BLANK COVER PLATE, U.N.C.

ALL CONDUITS SHALL BE 1" FOR ALL DEVICES UNLESS NOTED OTHERWISE ON THE TECHNOLOGY DRAWINGS.


IN AREAS WITH CONCRETE OR MASONRY WALLS, CONTRACTOR SHALL PROVIDE SURFACE RACEWAY SYSTEM.

IN AREAS WITH EXPOSED CEILINGS, CONTRACTOR SHALL INSTALL ALL CABLING IN CONDUIT. CONTRACTOR TO PERFORM PAINT FINISH AS COORDINATED WITH OWNER.

CONTRACTOR SHALL DEMOLISH ANY UNUSED CABLING BACK TO ITS ORIGIN AND DISPOSE.

CONTRACTOR SHALL REPLACE ALL EXISTING PTT BUTTONS PRESENT IN THE FACILITY WITH A BLANK COVER PLATE. CONTRACTOR SHALL LOCATE, DOCUMENT AND REMEDIATE IN THE SAME METHOD ANY PTT BUTTON NOT EXPLICITLY SHOWN IN THIS DRAWING SET.

CONTRACTOR IS RESPONSIBLE FOR PROVIDING LIFT FOR ALL HIGH CEILING AREAS (FINE ARTS, GYMS, ETC.). CONTRACTOR SHALL ALSO BE REQUIRED TO PROVIDE FLOORING PROTECTION.

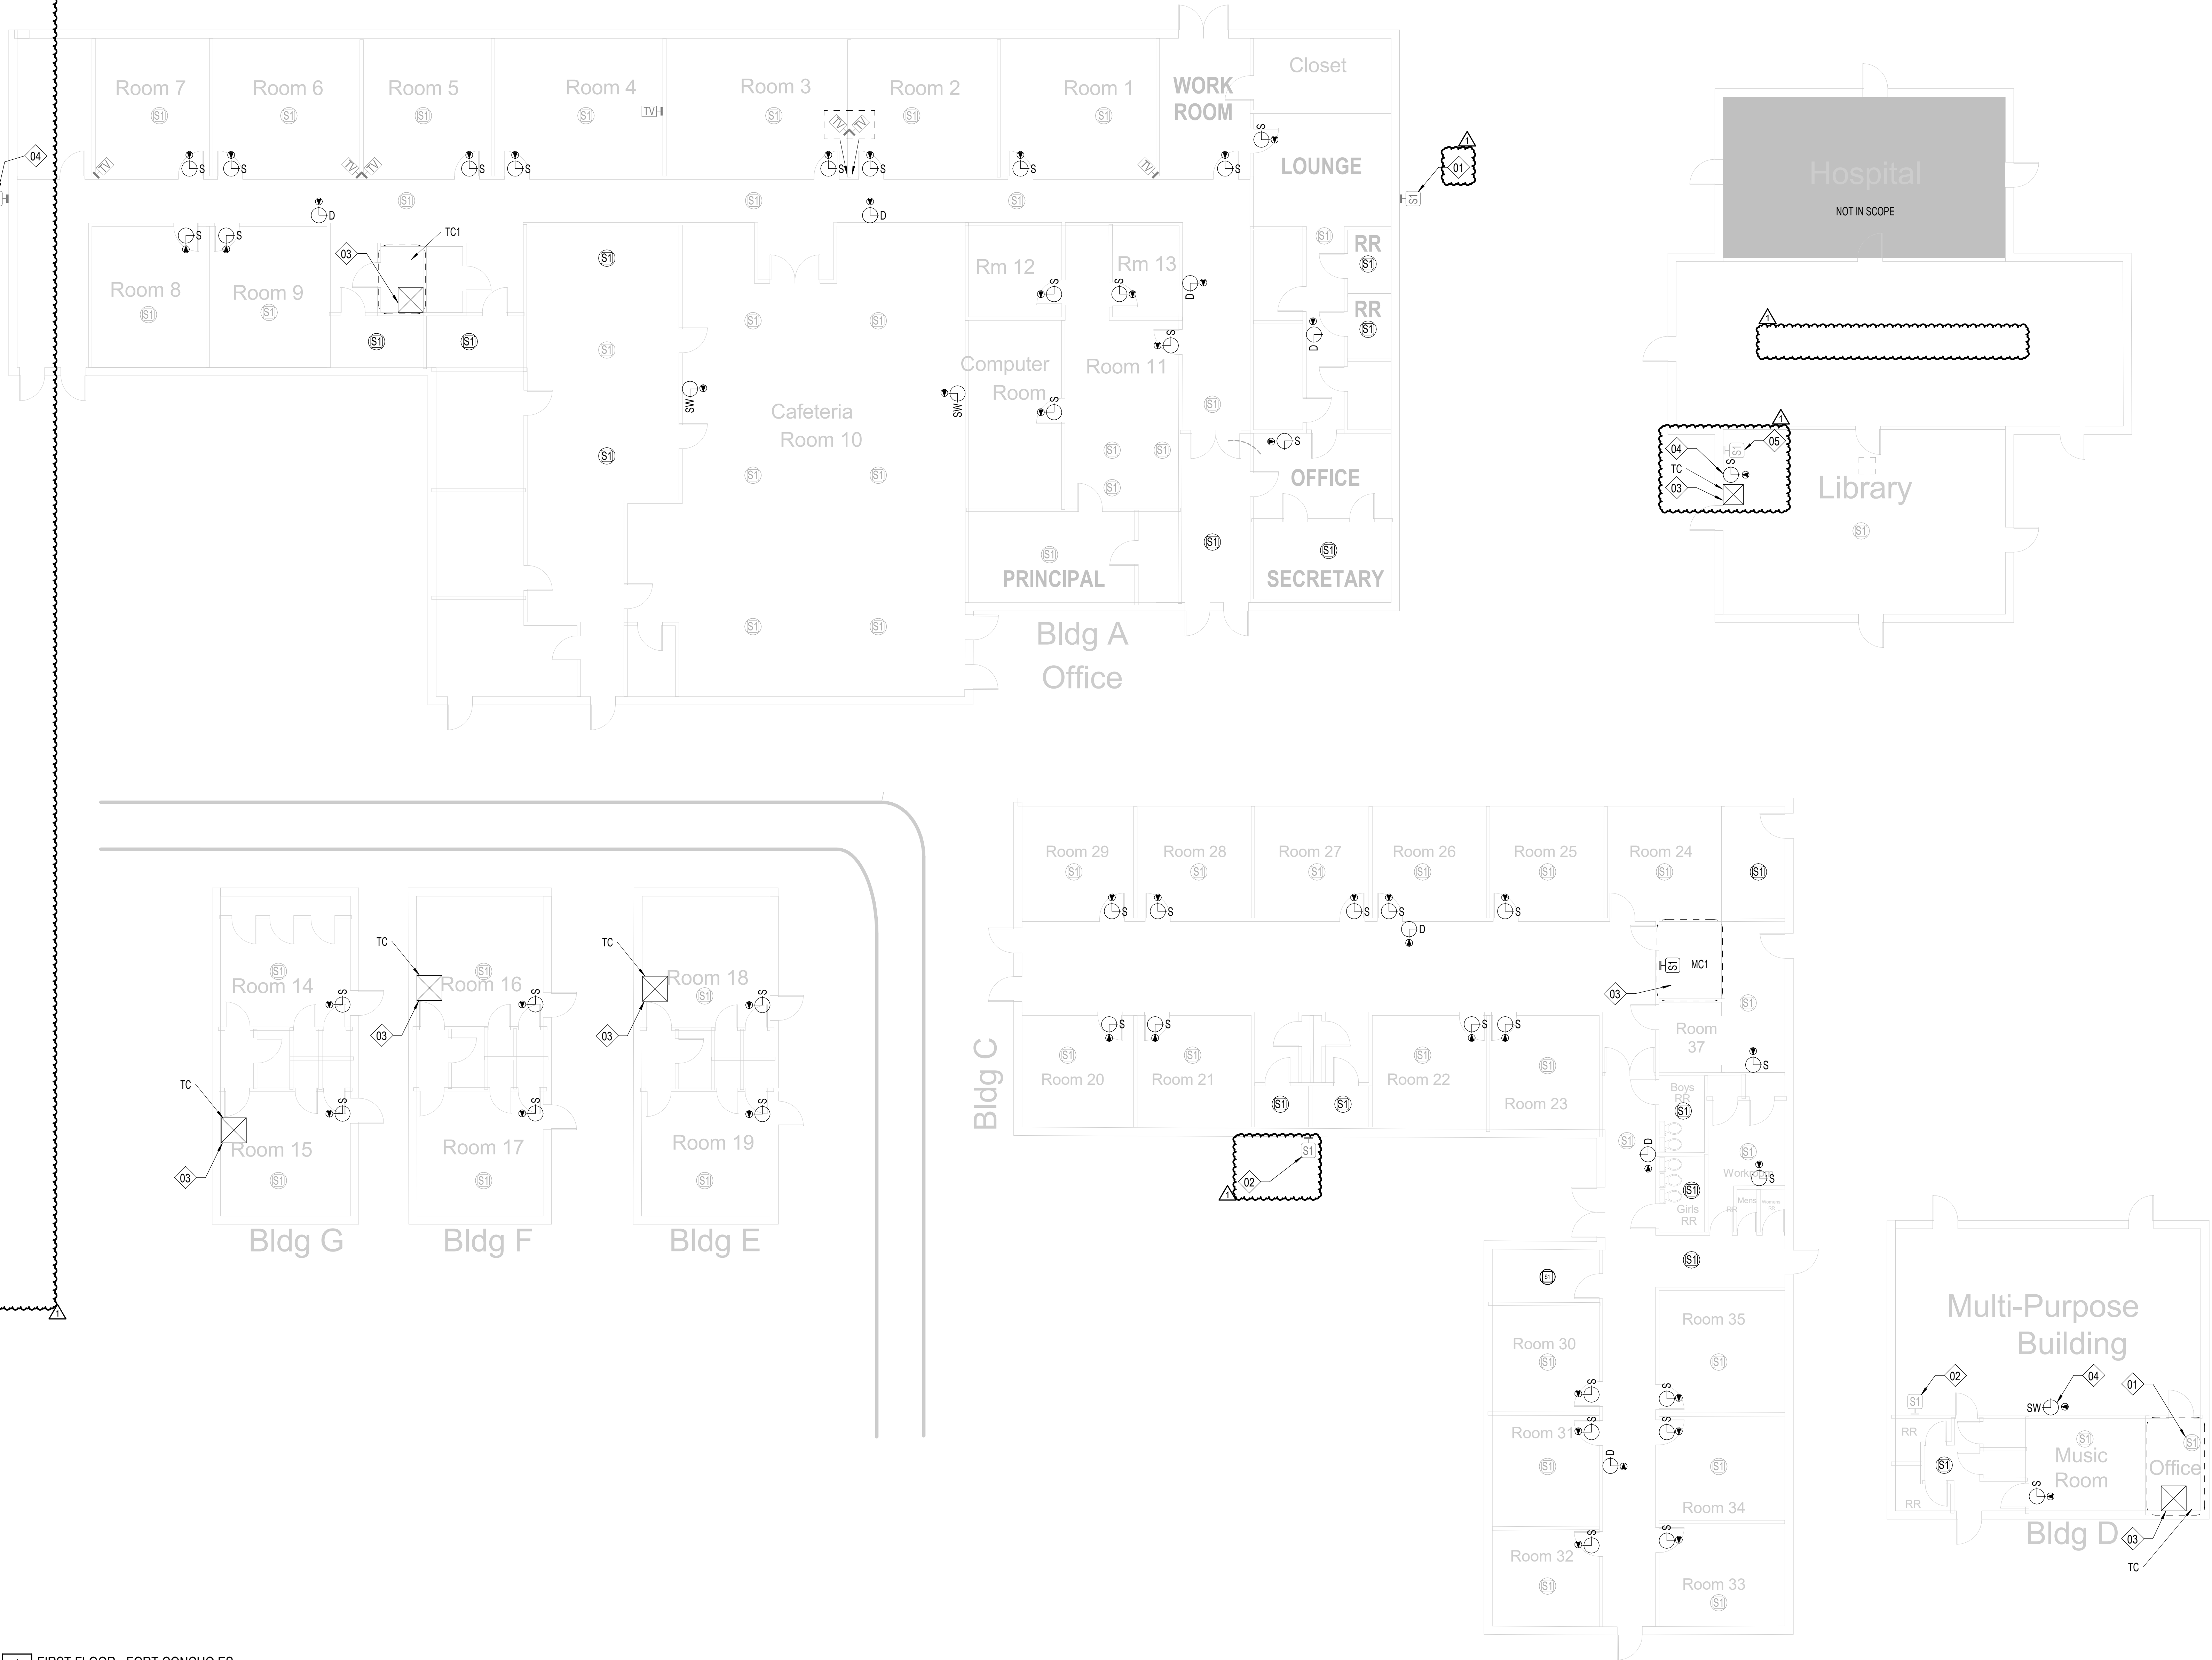

Description

Addendum 01

Date: 05/18/25

Revision: 1

SAN ANGELO ISD
PAGING UPGRADE
SAN ANGELO, TEXAS
D-SAN-1003-01

Project:



FLOOR PLAN - FORT CONCHO ES

Job No. D-SAN-1003-01
Drawn By: CV
Designed By: CV
Date: 04/29/2025
Sheet No. T127

Autosave Docs\CRUX-San Angelo ISD Paging System Upgrade\0-SAN-1003-01 SANSD ISD Paging Upgrade, TECH, 02\HOSTED.rvt

1	FLOOR PLAN - GLENMORE ES
T128	1/8" = 1'-0"

SHEET NOTES:

REFERENCE SHEET TG101 FOR ALL SYMBOLS AND PROJECT SPECIFIC NOTES.

EXISTING PAGING SPEAKERS (S1) ARE SHOWN IN HALFTONE. CONTRACTOR SHALL REMOVE EXISTING PAGING SPEAKERS (S1) AND REPLACE WITH CEILING TILE OR BLANK COVER PLATE, U.N.O.

ALL CONDUITS SHALL BE 1" FOR ALL DEVICES UNLESS NOTED OTHERWISE ON THE TECHNOLOGY DRAWINGS.

IN AREAS WITH CONCRETE OR MASONRY WALLS, CONTRACTOR SHALL PROVIDE SURFACE RACEWAY SYSTEM.

IN AREAS WITH EXPOSED CEILINGS, CONTRACTOR SHALL INSTALL ALL CABLING IN CONDUIT. CONTRACTOR TO PERFORM PAINT/FINISH AS COORDINATED WITH OWNER.

CONTRACTOR SHALL DEMOLISH ANY UNUSED CABLING BACK TO ITS ORIGIN AND DISPOSE.

CONTRACTOR SHALL REPLACE ALL EXISTING PTT BUTTONS PRESENT IN THE FACILITY WITH A BLANK COVER PLATE. CONTRACTOR SHALL LOCATE, DOCUMENT AND REMEDIATE IN THE SAME METHOD ANY PTT BUTTON NOT EXPLICITLY SHOWN IN THIS DRAWING SET.

CONTRACTOR IS RESPONSIBLE FOR PROVIDING LIFT FOR ALL HIGH CEILING AREAS (FINE ARTS, GYMS, ETC.). CONTRACTOR SHALL ALSO BE REQUIRED TO PROVIDE FLOORING PROTECTION.

KEYNOTE LEGEND

(NOT ALL KEYNOTES MAY APPLY)

01. EXISTING. CONTRACTOR SHALL REPLACE WITH NEW DEVICE AND NEW CABLING. CEILING TILE MAY REMAIN IN PLACE UNLESS DAMAGED.

02. EXISTING. TO REMAIN. CONTRACTOR SHALL INSTALL BRIDGE FROM ANALOG SPEAKER TO IP HEAD END.

03. CONTRACTOR SHALL COMPLETELY REMOVE ALL ABANDONED ANALOG SPEAKER WIRING AND SUPPORTING TERMINAL BLOCKS FROM THE FACILITY. TERMINAL BLOCKS THAT SUPPORT OTHER EXISTING DEVICES SHALL REMAIN.

04. INSTALL PLASTIC 1/2" RACEWAY FOR PATCH CABLE TO TOP OF SURFACE MOUNTED CLOCK BACK BOX. TERMINATE DATA ABOVE CEILING.

05. EXISTING. CONTRACTOR SHALL REMOVE DEVICE, DEMOLISH CABLING BACK TO ITS ORIGIN, AND INSTALL NEW BLANK FACEPLATE.

06. INSTALL DATA IN ADJACENT OVERHEAD CEILING SPACE. PROVIDE 1" SLEEVE THROUGH CMU WALL TO BACK OF CLOCK DISPLAY.

07. SURFACE MOUNTED CONDUIT NEEDED FOR ALL NEW PAGING AND RELATED DEVICES.

08. PROVIDE 1" CONDUIT TO TOP OF SURFACE MOUNTED CLOCK BACK BOX FOR PATCH CABLE. DATA SHALL BE TERMINATED ABOVE CEILING.

09. INSTALL SURFACE MOUNTED RACEWAY FROM DEVICE BACK TO TECH CLOSET LOCATION.

10. CEILING SPEAKER IN CAN MOUNTED TO STRUCTURAL STEEL.

11. THIS IS A PLASTER CEILING. CONDUIT OR PLASTIC RACEWAY WILL NEED TO BE SECURED TO THE CEILING ITSELF.

12. SPEAKERS MOUNTED TO STRUCTURAL STEEL.

13. INSTALL SURFACE RACEWAY FOR ENTIRE PATH FROM TC TO DEVICE.

14. EXISTING SPEAKER BUILT FLUSH IN WALL. DO NOT REMOVE. INSTALL NEW DEVICE ADJACENT TO EXISTING. INSTALL DATA DROP IN ACCESSIBLE CEILING IN ADJACENT SPACE.

15. REMOVE EXISTING HORNS AND LEAVE MOUNTS INTACT. REMOVE EXISTING CABLING. INSTALL NEW DUAL SIDED DEVICE ADJACENT TO FORMER HORN LOCATION. INSTALL DATA IN ADJACENT CEILING SPACE.

16. REFERENCE DIV 27 FOR RACK INFORMATION AND ALLOWANCE REQUIREMENTS. FINAL LOCATIONS TO BE COORDINATED WITH OWNER PRIOR TO INSTALLATION.


17. NOT USED.

18. RECENTLY INSTALLED SPEAKER. REMOVE, PROTECT, AND REDEPLOY WHERE OTHER NEW ANALOG CEILING SPEAKERS ARE NEEDED.

19. J-BOX LARGER THAN 4X4" NEEDED HERE. PROVIDE ADDITIONAL SLACK FOR FUTURE RETERMINATIONS.

20. FIELD CONDITIONS MAY DIFFER FROM WHAT IS SHOWN. COORDINATE EXACT LOCATION WITH OWNER.

21. GYP CEILING. CONTRACTOR SHALL ACCOUNT FOR THREE (3) 24"X24" ACCESS PANEL LOCATIONS IN PRICING. VERIFY PATHWAYS ON SITE.

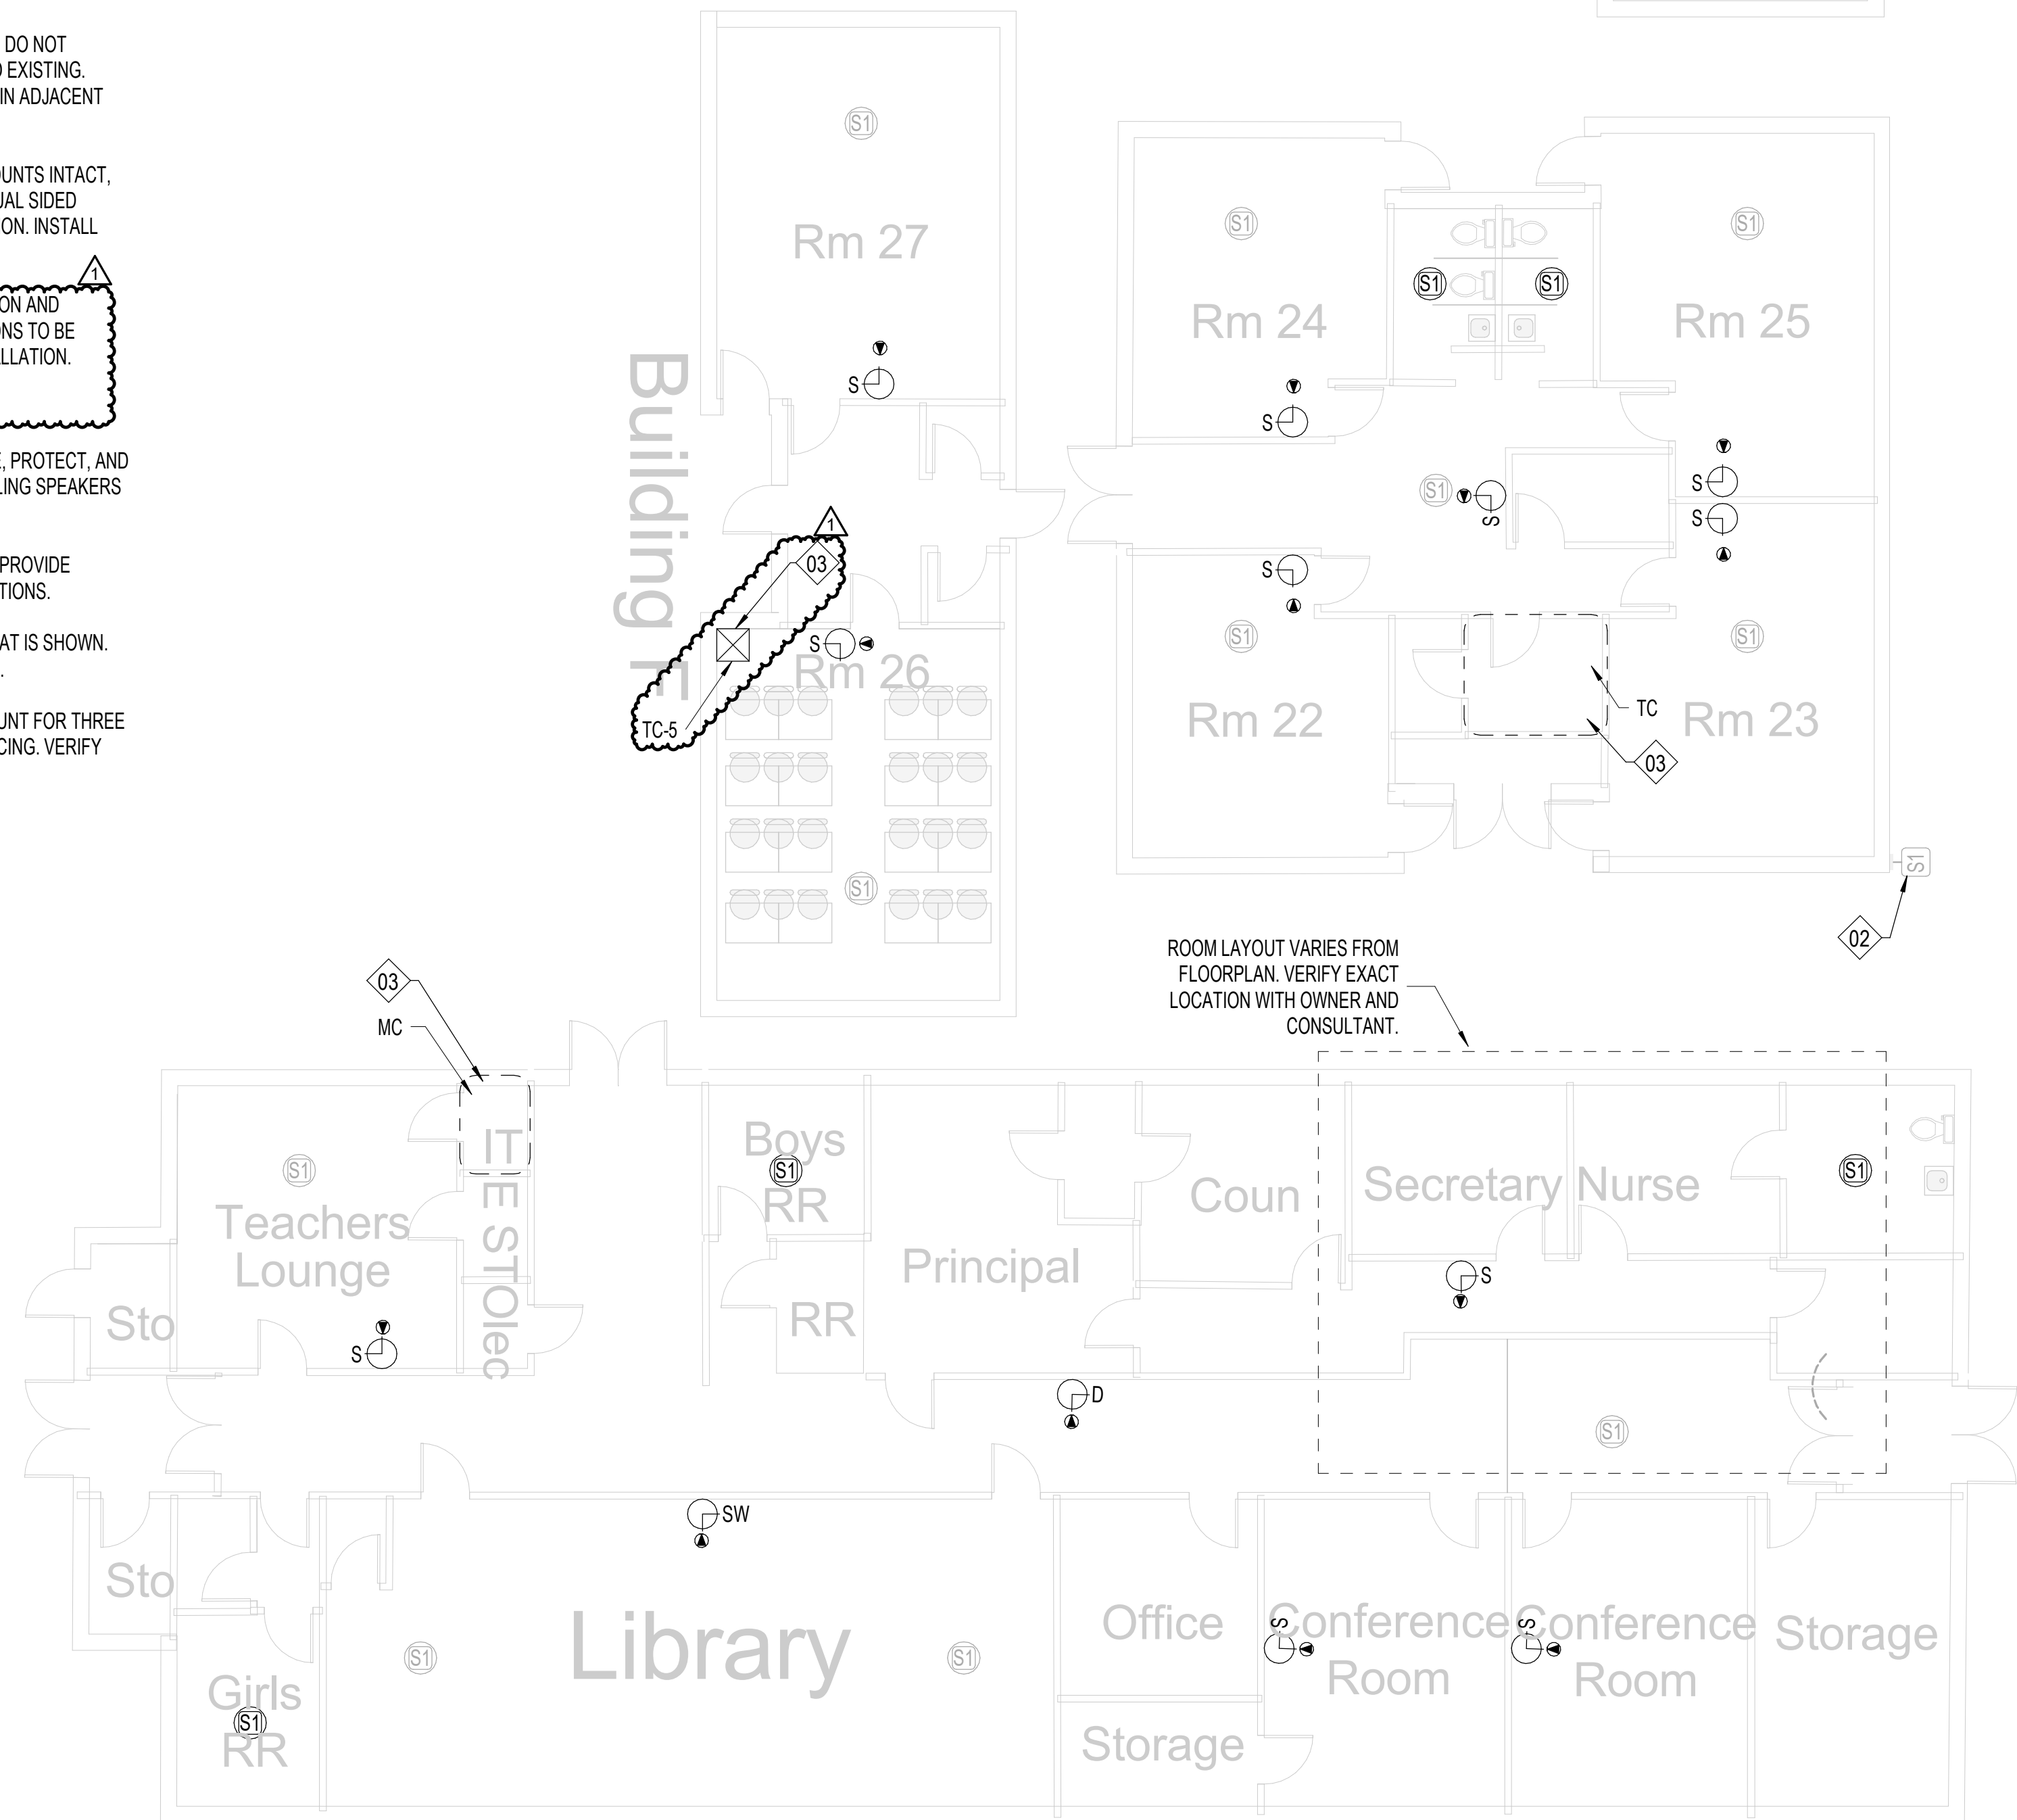

Description

Addendum 01

Date:

05/18/25

Revision:

1

SAN ANGELO ISD
PAGING UPGRADE
SAN ANGELO, TEXAS
D-SAN-1003-01

Project:



FLOOR PLAN - GLENMORE ES

Job No.

D-SAN-1003-01

Drawn By:

CV

Designed By:

CV

Date:


04/29/2025

Sheet No.

T128

Autosave Docs:CRUX-San Angelo ISD Paging System Upgrade\B SAN-1003-01 SANSD ISD Paging Upgrade, TECH, 02\HOSTED.rvt

1 FLOOR PLAN - GOLIAD ES
1109 1" = 10'-0"

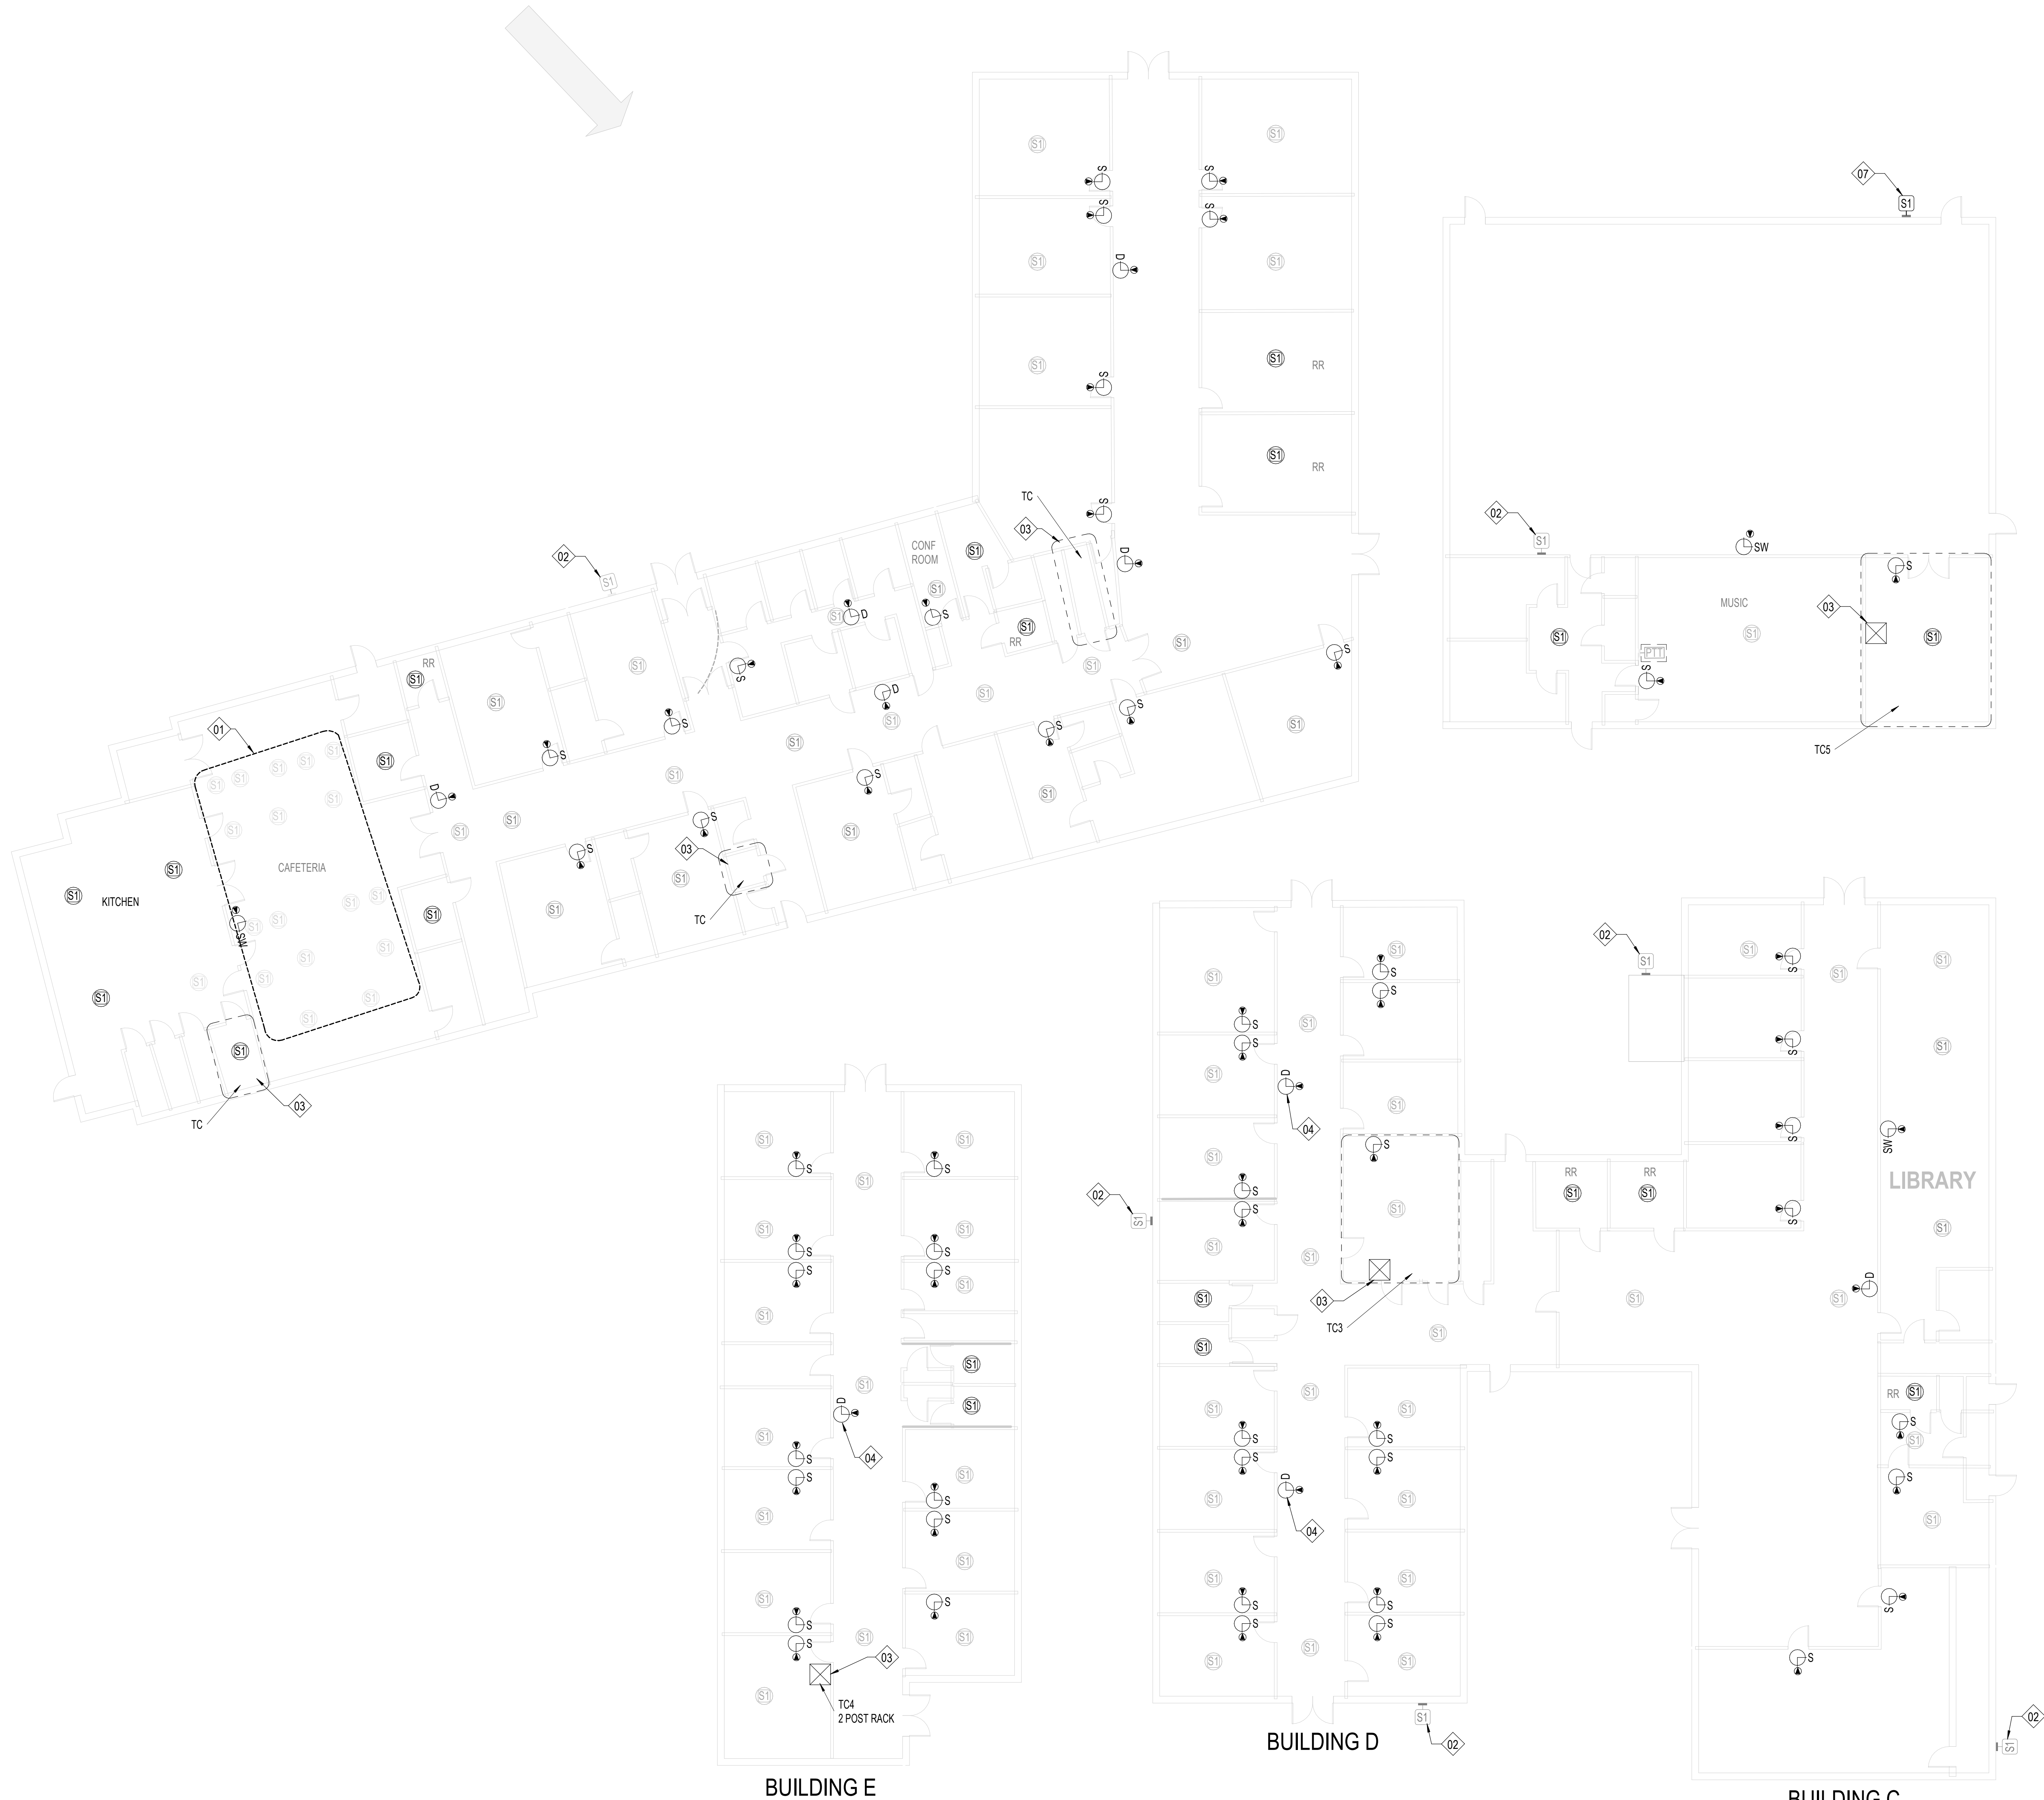

SHEET NOTES:

REFERENCE SHEET TG101 FOR ALL SYMBOLS AND PROJECT SPECIFIC NOTES.

EXISTING PAGING SPEAKERS (S1) ARE SHOWN IN HALF-TONE. CONTRACTOR SHALL REMOVE EXISTING PAGING SPEAKERS (S1) AND REPLACE WITH CEILING TILE OR BLANK COVER PLATE, UNO.

ALL CONDUITS SHALL BE 1" FOR ALL DEVICES UNLESS NOTED OTHERWISE ON THE TECHNOLOGY DRAWINGS.

IN AREAS WITH CONCRETE OR MASONRY WALLS, CONTRACTOR SHALL PROVIDE SURFACE RACEWAY SYSTEM.

IN AREAS WITH EXPOSED CEILINGS, CONTRACTOR SHALL INSTALL ALL CABLING IN CONDUIT. CONTRACTOR TO PERFORM PAINT FINISH AS COORDINATED WITH OWNER.

CONTRACTOR SHALL DEMOLISH ANY UNUSED CABLING BACK TO ITS ORIGIN AND DISPOSE.

CONTRACTOR SHALL REPLACE ALL EXISTING PTT BUTTONS PRESENT IN THE FACILITY WITH A BLANK COVER PLATE. CONTRACTOR SHALL LOCATE, DOCUMENT AND REMEDIATE IN THE SAME METHOD ANY PTT BUTTON NOT EXPLICITLY SHOWN IN THIS DRAWING SET.

CONTRACTOR IS RESPONSIBLE FOR PROVIDING LIFT FOR ALL HIGH CEILING AREAS (FINE ARTS, GYM, ETC.). CONTRACTOR SHALL ALSO BE REQUIRED TO PROVIDE FLOORING PROTECTION.

KEYNOTE LEGEND

(NOT ALL KEYNOTES MAY APPLY.)

01. EXISTING, CONTRACTOR SHALL REPLACE WITH NEW DEVICE AND NEW CABLING. CEILING TILE MAY REMAIN IN PLACE UNLESS DAMAGED.

02. EXISTING, TO REMAIN. CONTRACTOR SHALL INSTALL BRIDGE FROM ANALOG SPEAKER TO IP HEAD END.

03. CONTRACTOR SHALL COMPLETELY REMOVE ALL ABANDONED ANALOG SPEAKER WIRING AND SUPPORTING TERMINAL BLOCKS FROM THE FACILITY. TERMINAL BLOCKS THAT SUPPORT OTHER EXISTING DEVICES SHALL REMAIN.

04. INSTALL PLASTIC 1/2" RACEWAY FOR PATCH CABLE TO TOP OF SURFACE MOUNTED CLOCK BACK BOX. TERMINATE DATA ABOVE CEILING.

05. EXISTING, CONTRACTOR SHALL REMOVE DEVICE, DEMOLISH CABLING BACK TO ITS ORIGIN, AND INSTALL NEW BLANK FACEPLATE.

06. INSTALL DATA IN ADJACENT OVERHEAD CEILING SPACE. PROVIDE 1" SLEEVE THROUGH CMU WALL TO BACK OF CLOCK DISPLAY.

07. SURFACE MOUNTED CONDUIT NEEDED FOR ALL NEW PAGING AND RELATED DEVICES.

08. PROVIDE 1" CONDUIT TO TOP OF SURFACE MOUNTED CLOCK BACK BOX FOR PATCH CABLE. DATA SHALL BE TERMINATED ABOVE CEILING.

09. INSTALL SURFACE MOUNTED RACEWAY FROM DEVICE BACK TO TECH CLOSET LOCATION.

10. CEILING SPEAKER IN CAN MOUNTED TO STRUCTURAL STEEL.

11. THIS IS A PLASTER CEILING, CONDUIT OR PLASTIC RACEWAY WILL NEED TO BE SECURED TO THE CEILING ITSELF.

12. SPEAKERS MOUNTED TO STRUCTURAL STEEL.

13. INSTALL SURFACE RACEWAY FOR ENTIRE PATH FROM TC TO DEVICE.

14. EXISTING SPEAKER BUILT FLUSH IN WALL. DO NOT REMOVE. INSTALL NEW DEVICE ADJACENT TO EXISTING. INSTALL DATA DROP IN ACCESSIBLE CEILING IN ADJACENT SPACE.

15. REMOVE EXISTING HORNS AND LEAVE MOUNTS INTACT. REMOVE EXISTING CABLING. INSTALL NEW DUAL SIDED DEVICE ADJACENT TO FORMER HORN LOCATION. INSTALL DATA IN ADJACENT CEILING SPACE.

16. REFERENCE DIV 27 FOR RACK INFORMATION AND ALLOWANCE REQUIREMENTS. FINAL LOCATIONS TO BE COORDINATED WITH OWNER PRIOR TO INSTALLATION.

17. NOT USED.

18. RECENTLY INSTALLED SPEAKER. REMOVE, PROTECT, AND REDEPLOY WHERE OTHER NEW ANALOG CEILING SPEAKERS ARE NEEDED.

19. J-BOX LARGER THAN 4X4" NEEDED HERE. PROVIDE ADDITIONAL SLACK FOR FUTURE RETERMINATIONS.

20. FIELD CONDITIONS MAY DIFFER FROM WHAT IS SHOWN. COORDINATE EXACT LOCATION WITH OWNER.

21. GYP CEILING. CONTRACTOR SHALL ACCOUNT FOR THREE (3) 24"x24" ACCESS PANEL LOCATIONS IN PRICING. VERIFY PATHWAYS ON SITE.

Description

Addendum 01

Date: 05/18/25

Revision: 1

Project:

SAN ANGELO ISD
PAGING UPGRADE
SAN ANGELO, TEXAS
D-SAN-1003-01



CRUX
TECHNOLOGY • SECURITY SOLUTIONS
800.665.6440
www.cruxsolutions.com

FLOOR PLAN - GOLIAD ES

Job No.

D-SAN-1003-01

Drawn By:

CV

Designed By:


CV

Date:

04/29/2025

Sheet No.

T129

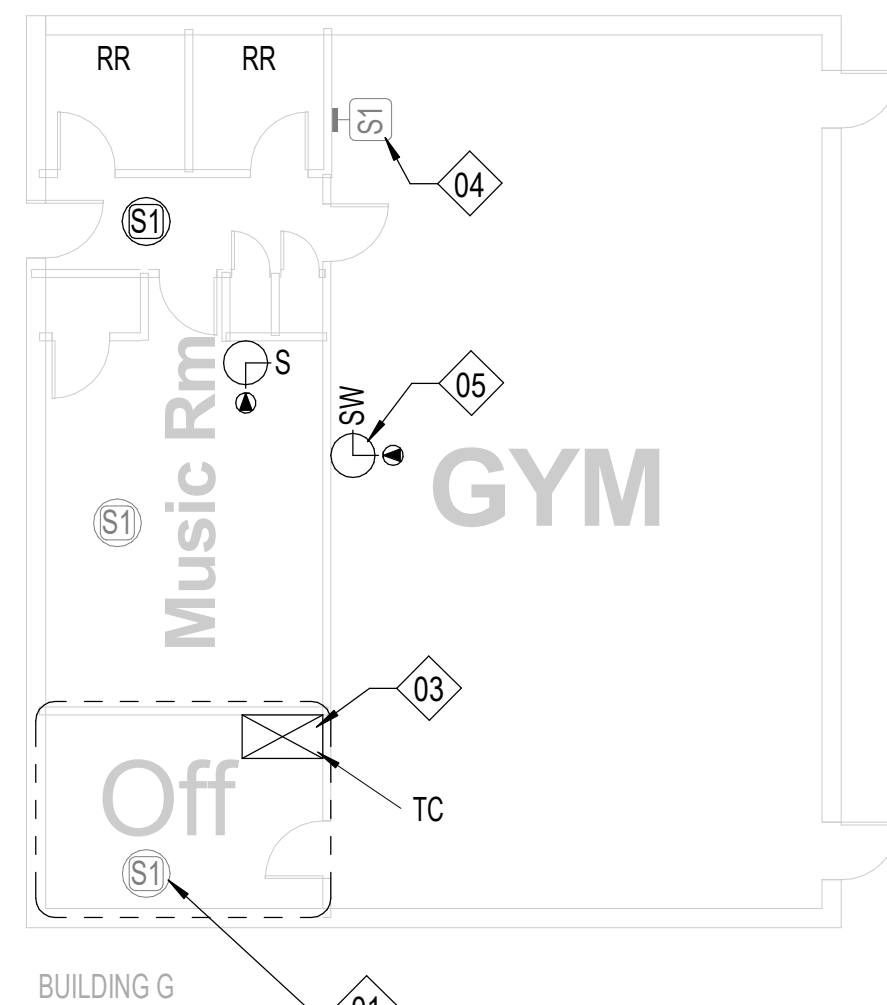

T130

SAN ANGELO ISD
PAGING UPGRADE
SAN ANGELO, TEXAS
D-SAN-1003-01





21. GYP CEILING. CONTRACTOR SHALL ACCOUNT FOR THREE (3) 24"x24" ACCESS PANEL LOCATIONS IN PRICING. VERIFY PATHWAYS ON SITE.

Sheet No.

Autodesk Docs\CRUX-San Angelo ISD Paging System Upgrade\B SAN-100-01 SANSD ISD Paging Upgrade, TECH, 02\HOSTED\1.rvt

1 FLOOR PLAN - LINCOLN MS
T133 1/4" = 1'-0"

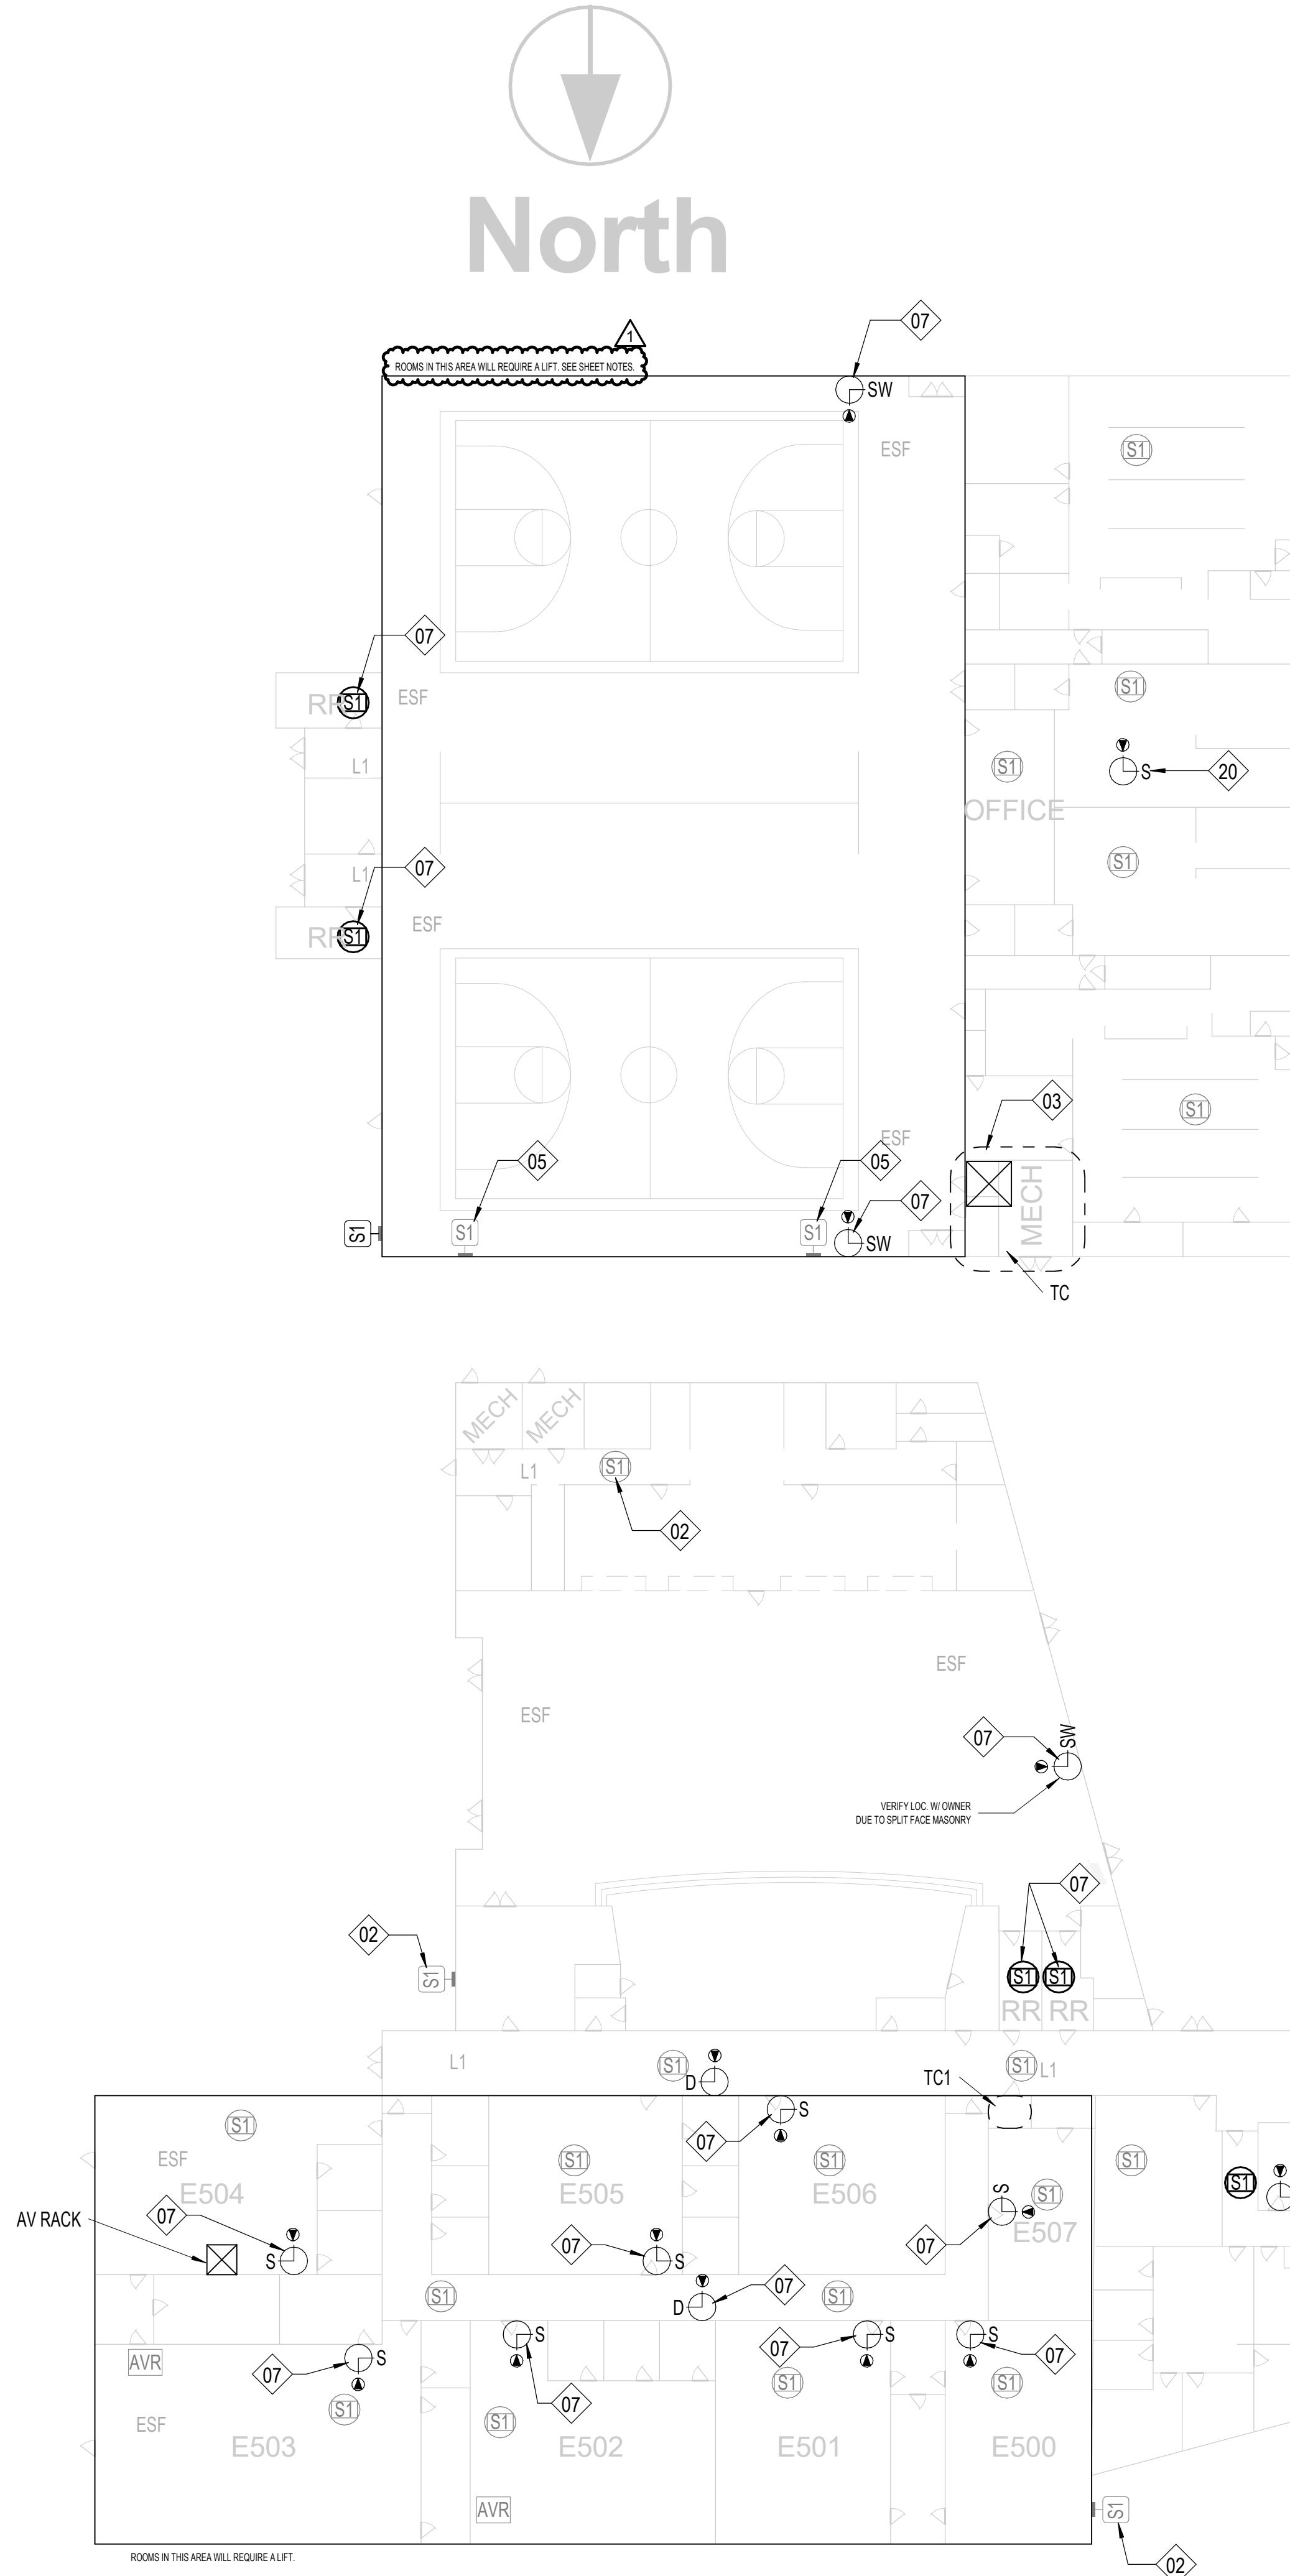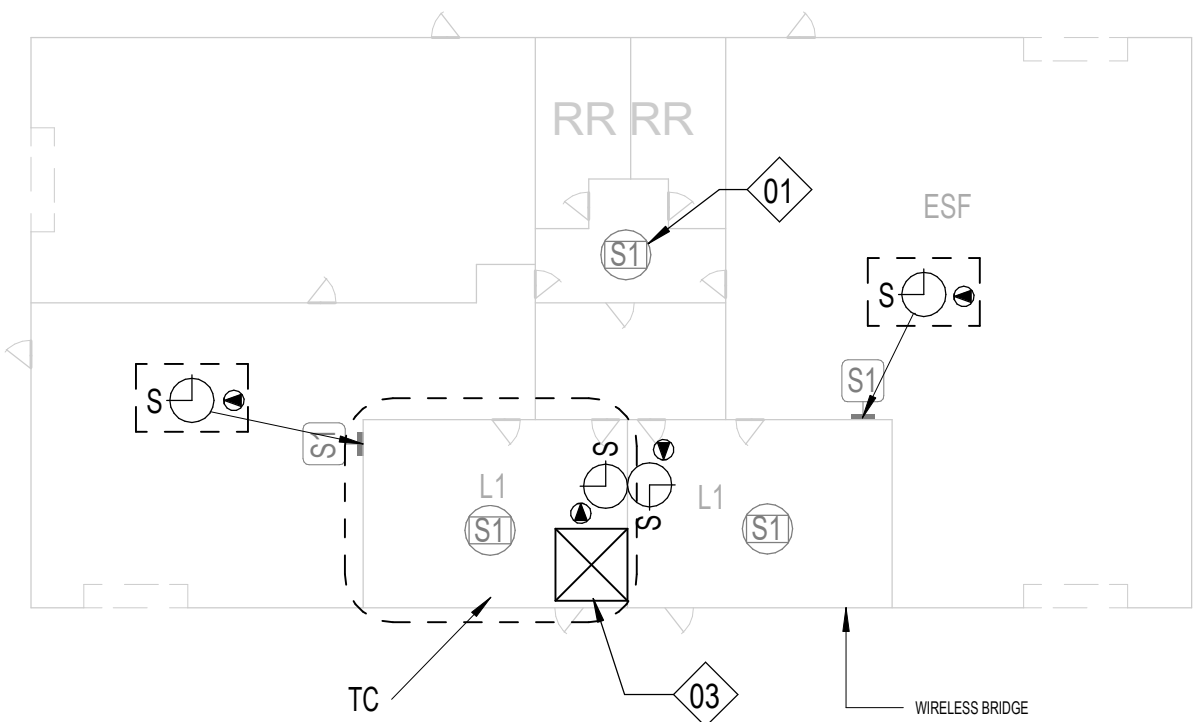

KEYNOTE LEGEND

(NOT ALL KEYNOTES MAY APPLY.)

- EXISTING, CONTRACTOR SHALL REPLACE WITH NEW DEVICE AND NEW CABLING. CEILING TILE MAY REMAIN IN PLACE UNLESS DAMAGED.
- EXISTING, TO REMAIN. CONTRACTOR SHALL INSTALL BRIDGE FROM ANALOG SPEAKER TO IP HEAD END.
- CONTRACTOR SHALL COMPLETELY REMOVE ALL ABANDONED ANALOG SPEAKER WIRING AND SUPPORTING TERMINAL BLOCKS FROM THE FACILITY. TERMINAL BLOCKS THAT SUPPORT OTHER EXISTING DEVICES SHALL REMAIN.
- INSTALL PLASTIC 1/2" RACEWAY FOR PATCH CABLE TO TOP OF SURFACE MOUNTED CLOCK BACK BOX. TERMINATE DATA ABOVE CEILING.
- EXISTING, CONTRACTOR SHALL REMOVE DEVICE. DEMOLISH CABLING BACK TO ITS ORIGIN, AND INSTALL NEW BLANK FACEPLATE.
- INSTALL DATA IN ADJACENT OVERHEAD CEILING SPACE. PROVIDE 1" SLEEVE THROUGH CMU WALL TO BACK OF CLOCK DISPLAY.
- SURFACE MOUNTED CONDUIT NEEDED FOR ALL NEW PAGING AND RELATED DEVICES.
- PROVIDE 1" CONDUIT TO TOP OF SURFACE MOUNTED CLOCK BACK BOX FOR PATCH CABLE. DATA SHALL BE TERMINATED ABOVE CEILING.
- INSTALL SURFACE MOUNTED RACEWAY FROM DEVICE BACK TO TECH CLOSET LOCATION.
- CEILING SPEAKER IN CAN MOUNTED TO STRUCTURAL STEEL.
- THIS IS A PLASTER CEILING, CONDUIT OR PLASTIC RACEWAY WILL NEED TO BE SECURED TO THE CEILING ITSELF.
- SPEAKERS MOUNTED TO STRUCTURAL STEEL.
- INSTALL SURFACE RACEWAY FOR ENTIRE PATH FROM TC TO DEVICE.
- EXISTING SPEAKER BUILT FLUSH IN WALL. DO NOT REMOVE. INSTALL NEW DEVICE ADJACENT TO EXISTING. INSTALL DATA DROP IN ACCESSIBLE CEILING IN ADJACENT SPACE.
- REMOVE EXISTING HORNS AND LEAVE MOUNTS INTACT. REMOVE EXISTING CABLING. INSTALL NEW DUAL SIDED DEVICE ADJACENT TO FORMER HORN LOCATION. INSTALL DATA IN ADJACENT CEILING SPACE.
- REFERENCE DIV 27 FOR RACK INFORMATION AND ALLOWANCE REQUIREMENTS. FINAL LOCATIONS TO BE COORDINATED WITH OWNER PRIOR TO INSTALLATION.
- NOT USED.
- RECENTLY INSTALLED SPEAKER. REMOVE, PROTECT, AND REDEPLOY WHERE OTHER NEW ANALOG CEILING SPEAKERS ARE NEEDED.
- J-BOX LARGER THAN 4X4" NEEDED HERE. PROVIDE ADDITIONAL SLACK FOR FUTURE RETERMINATIONS.
- FIELD CONDITIONS MAY DIFFER FROM WHAT IS SHOWN. COORDINATE EXACT LOCATION WITH OWNER.
- GYP CEILING. CONTRACTOR SHALL ACCOUNT FOR THREE (3) 24"x24" ACCESS PANEL LOCATIONS IN PRICING. VERIFY PATHWAYS ON SITE.



SHEET NOTES:

REFERENCE SHEET TG101 FOR ALL SYMBOLS AND PROJECT SPECIFIC NOTES.

EXISTING PAGING SPEAKERS (S1) ARE SHOWN IN HALFTONE. CONTRACTOR SHALL REMOVE EXISTING PAGING SPEAKERS (S1) AND REPLACE WITH CEILING TILE OR BLANK COVER PLATE, U.N.O.

ALL CONDUITS SHALL BE 1" FOR ALL DEVICES UNLESS NOTED OTHERWISE ON THE TECHNOLOGY DRAWINGS.


IN AREAS WITH CONCRETE OR MASONRY WALLS, CONTRACTOR SHALL PROVIDE SURFACE RACEWAY SYSTEM.

IN AREAS WITH EXPOSED CEILINGS, CONTRACTOR SHALL INSTALL ALL CABLING IN CONDUIT. CONTRACTOR TO PERFORM PAINT FINISH AS COORDINATED WITH OWNER.

CONTRACTOR SHALL DEMOLISH ANY UNUSED CABLING BACK TO ITS ORIGIN AND DISPOSE.

CONTRACTOR SHALL REPLACE ALL EXISTING PTT BUTTONS PRESENT IN THE FACILITY WITH A BLANK COVER PLATE. CONTRACTOR SHALL LOCATE, DOCUMENT AND REMEDIATE IN THE SAME METHOD ANY PTT BUTTON NOT EXPLICITLY SHOWN IN THIS DRAWING SET.

CONTRACTOR IS RESPONSIBLE FOR PROVIDING LIFT FOR ALL HIGH CEILING AREAS (FINE ARTS, GYMS, ETC.). CONTRACTOR SHALL ALSO BE REQUIRED TO PROVIDE FLOORING PROTECTION.

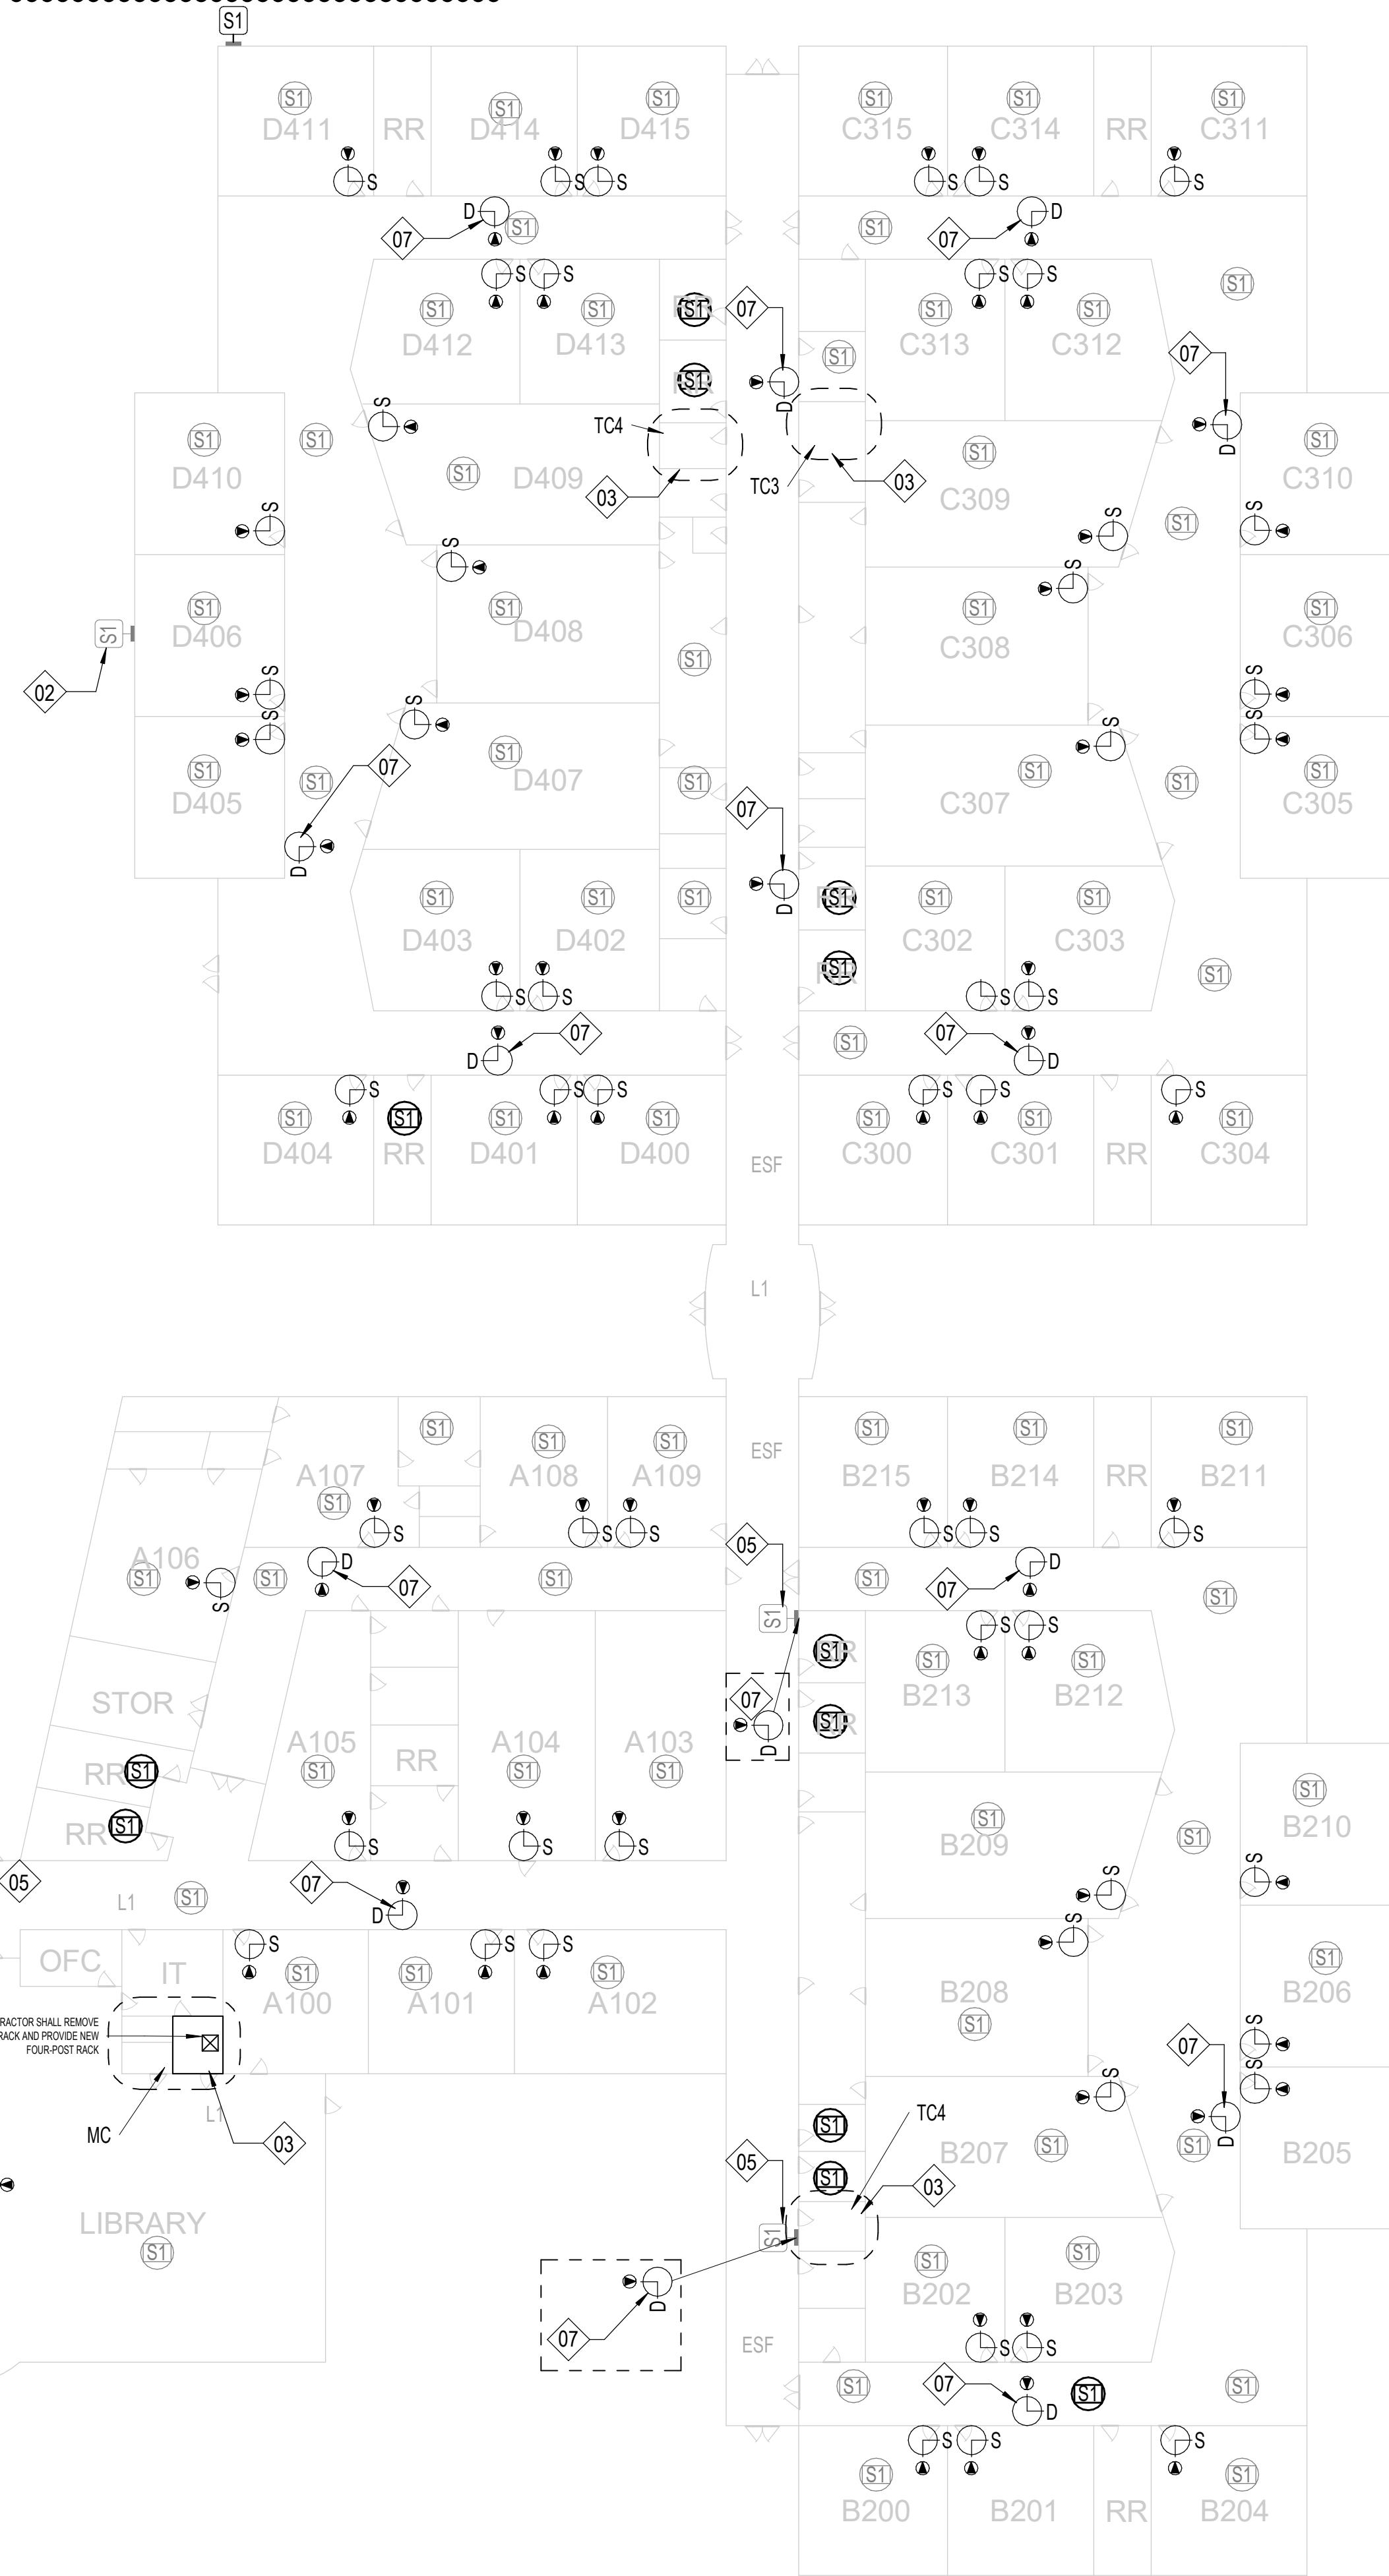

Description

Addendum 01

Date: 05/18/25

Revision: 1

Project:

SAN ANGELO ISD
PAGING UPGRADE
SAN ANGELO, TEXAS
D-SAN-1003-01




FLOOR PLAN - LINCOLN MS







Job No.
D-SAN-1003-01
Drawn By:
CV
Designed By:
CV
Date:
04/29/2025

Sheet No.
T133

Second Floor

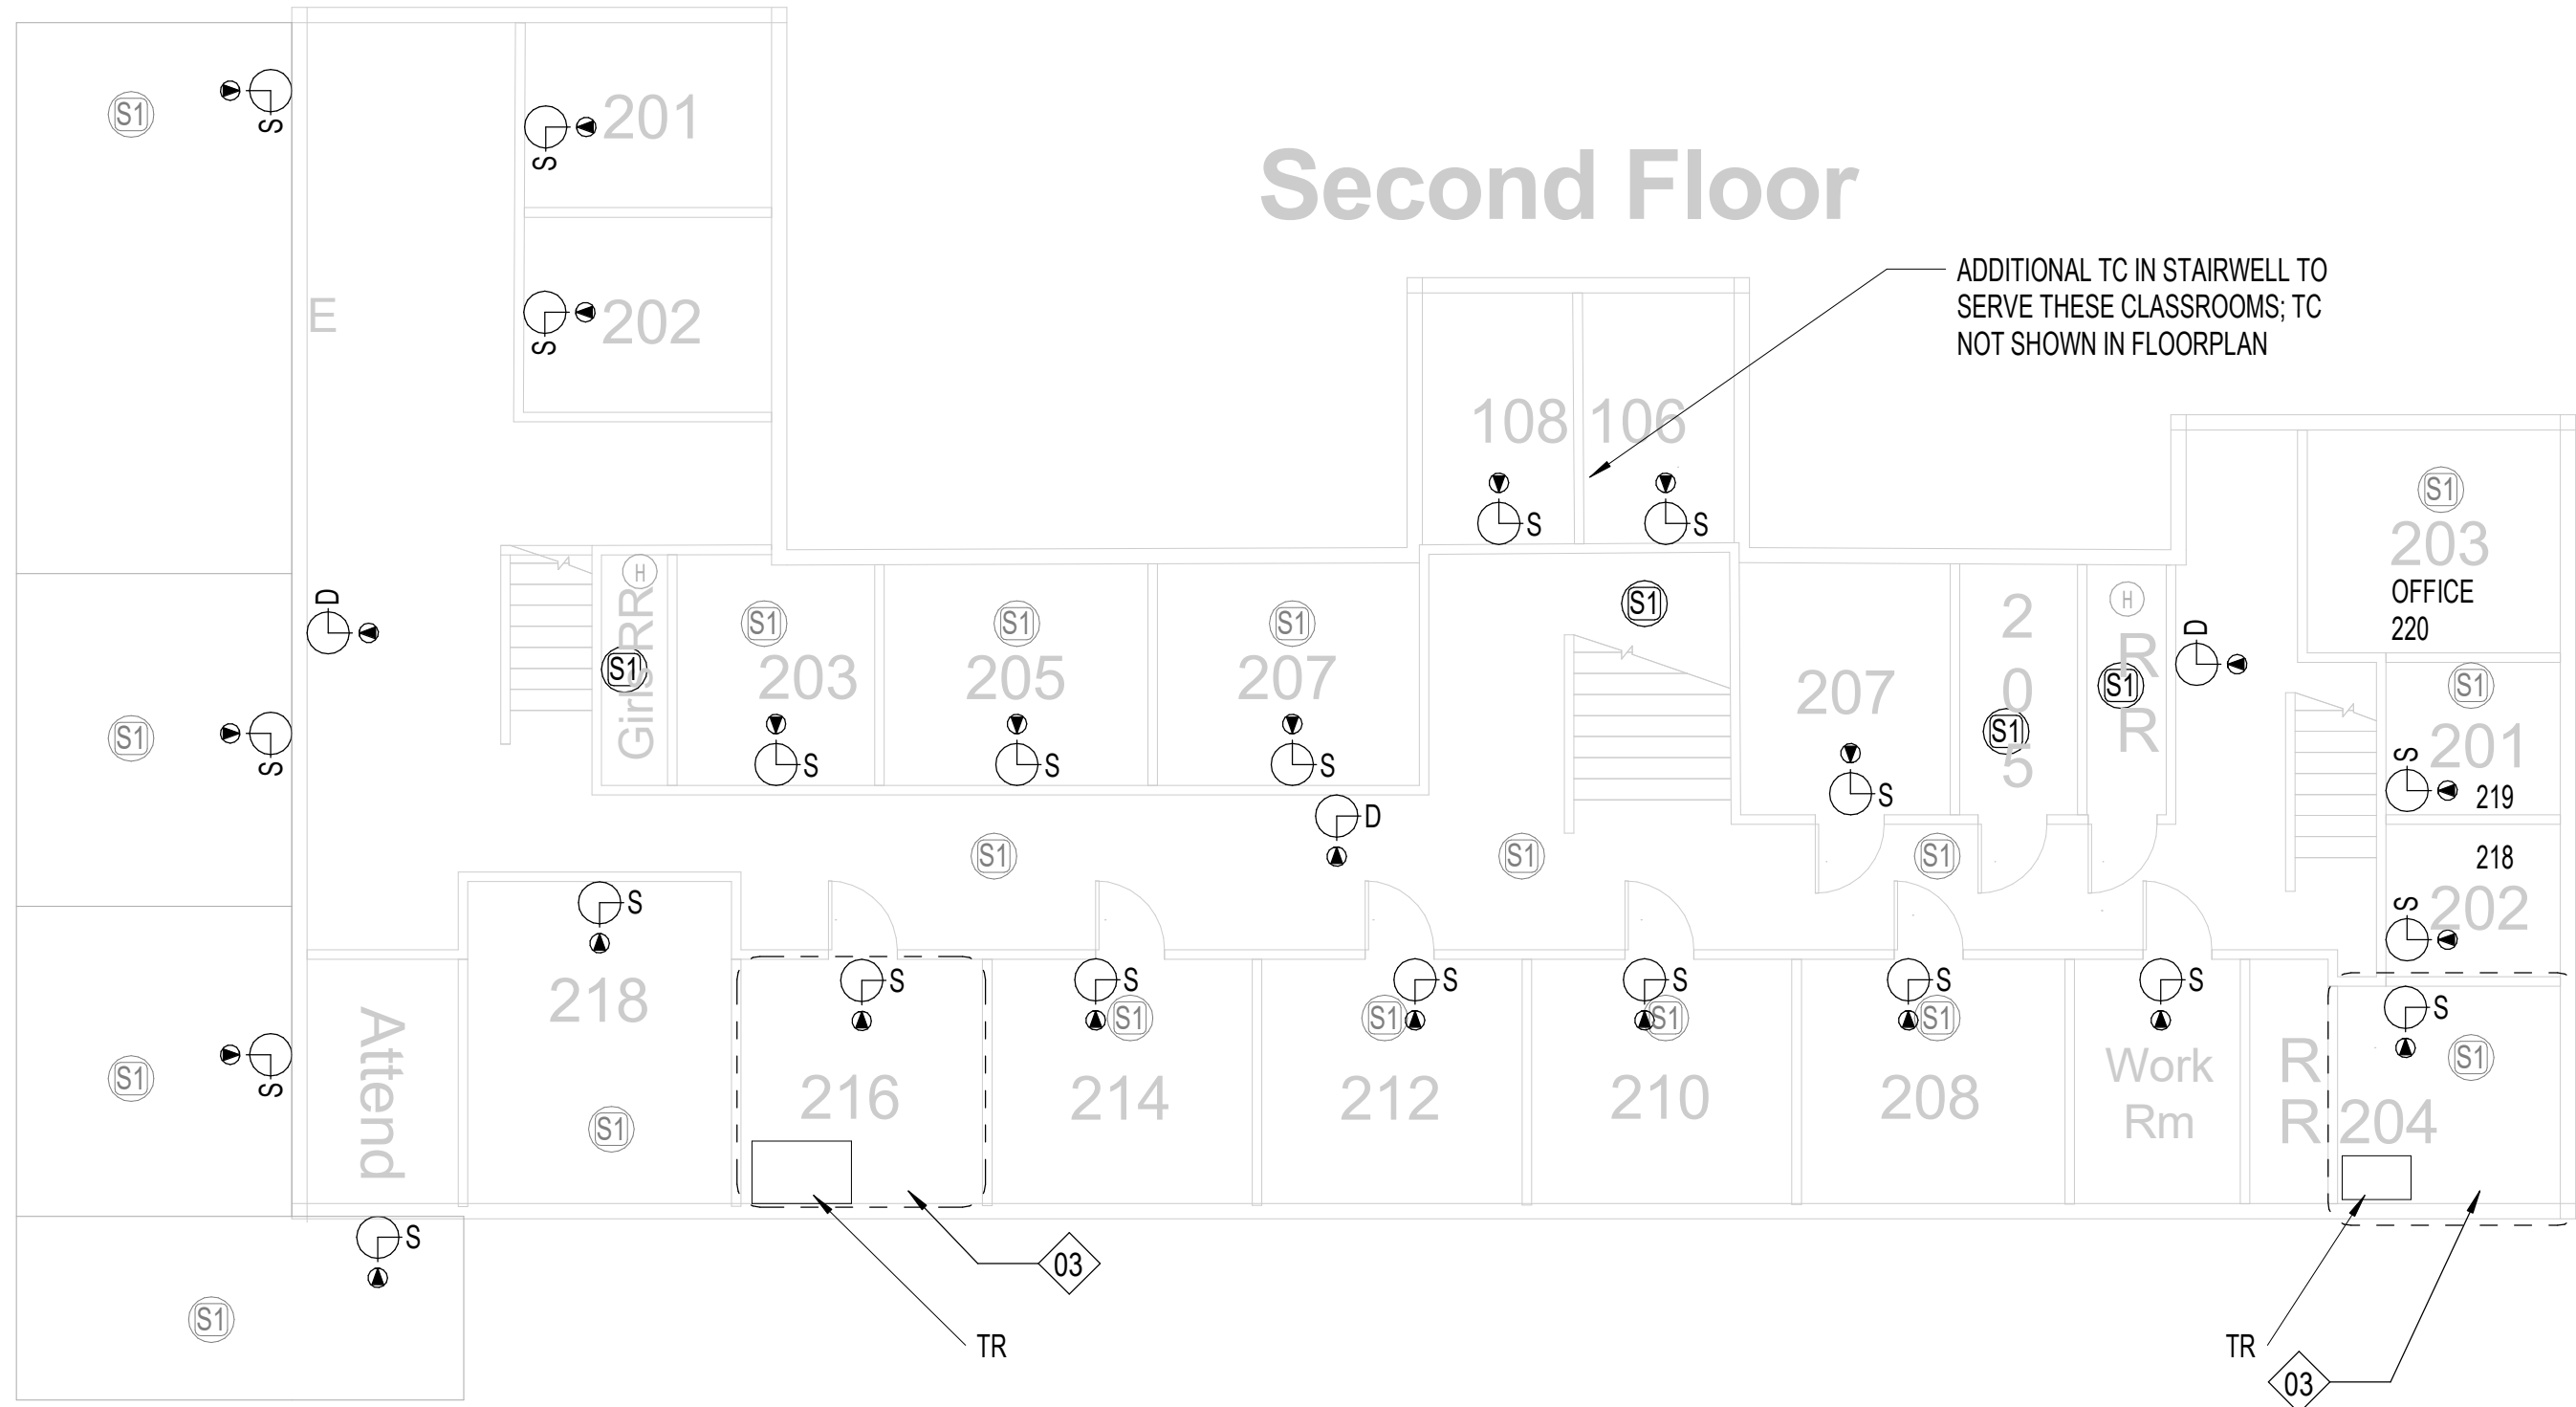

WEIGHT ROOM NOT DEPICTED, PROVIDE WIDE CLOCK WITH NEW CABLING AND PATHWAY. COORDINATE EXACT LOCATION WITH OWNER & CONSULTANT.

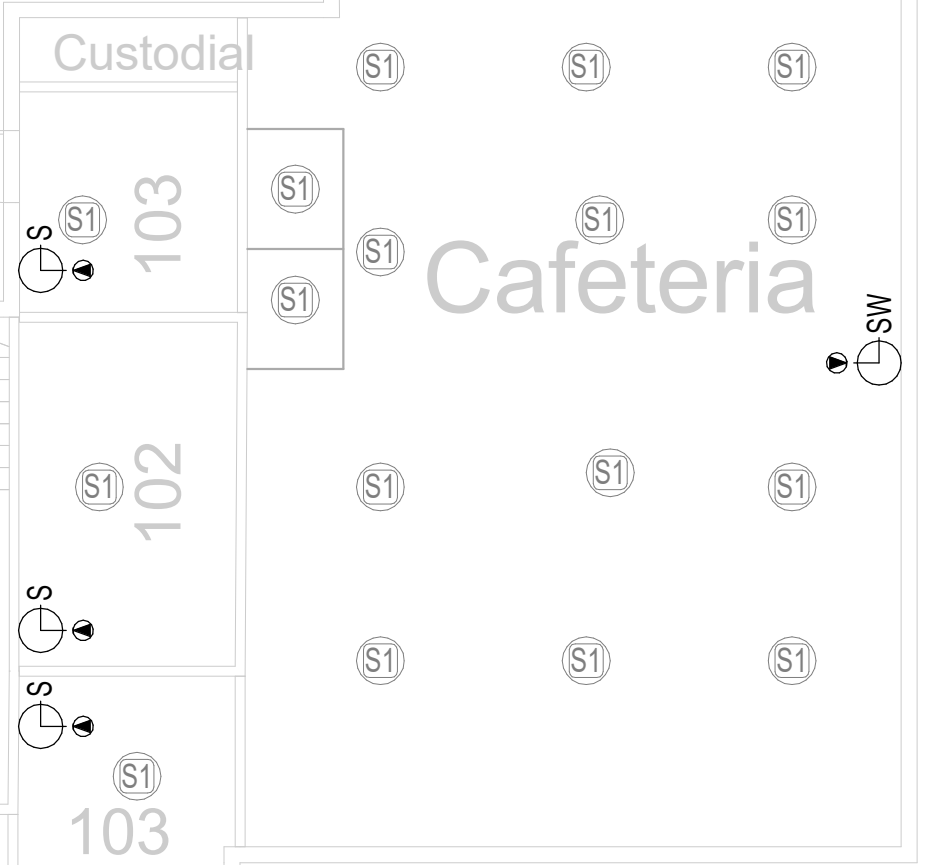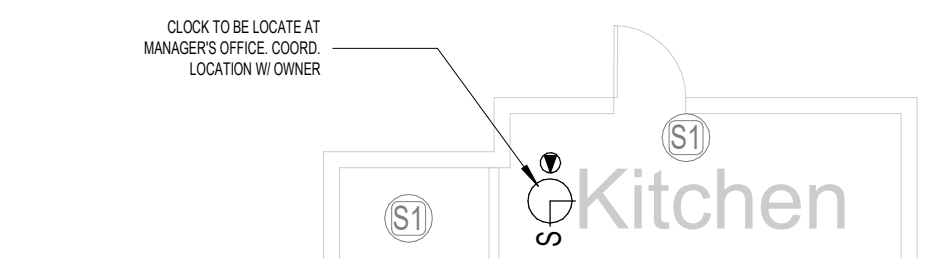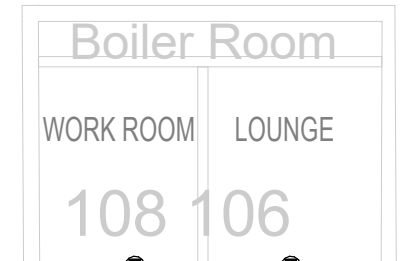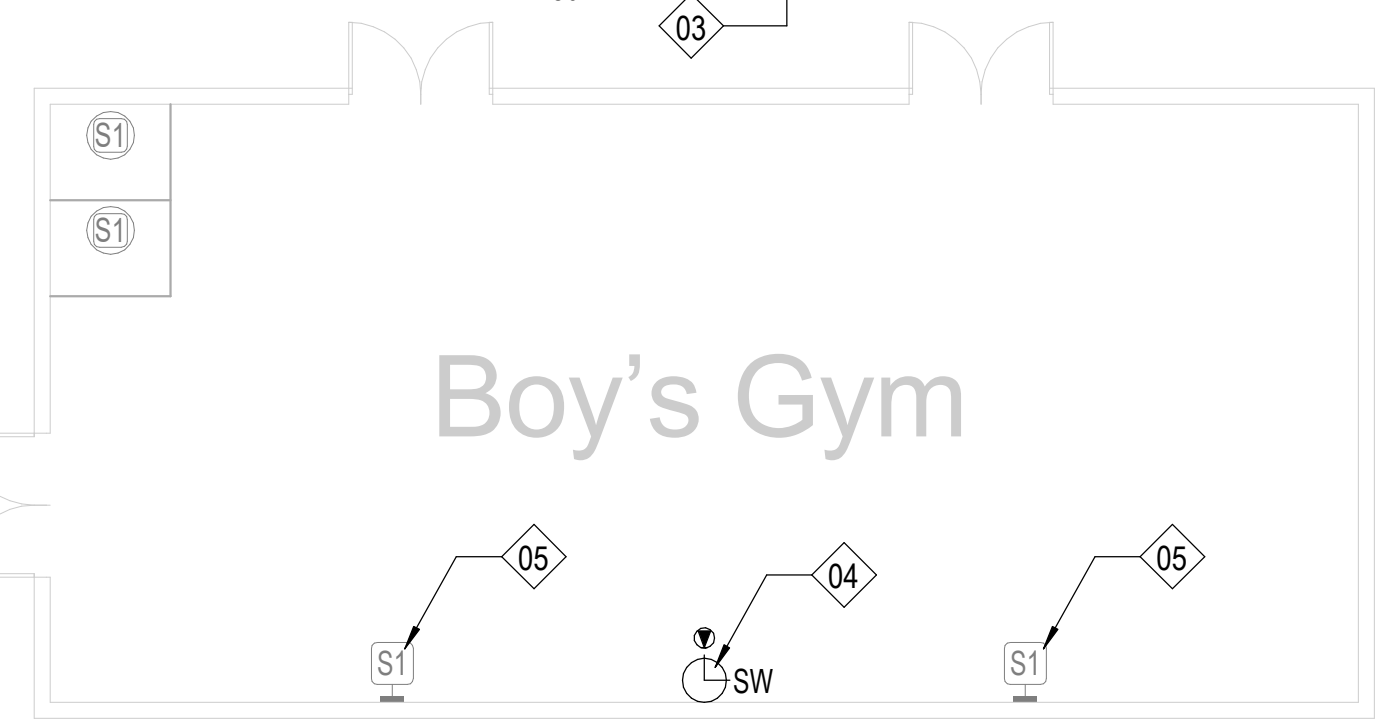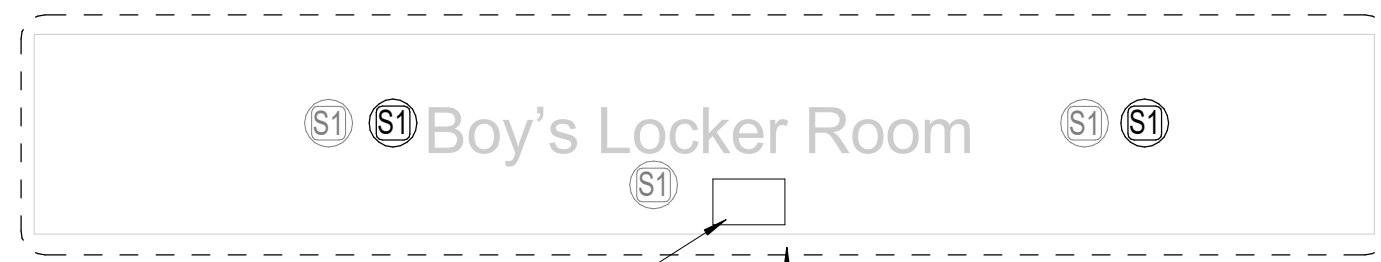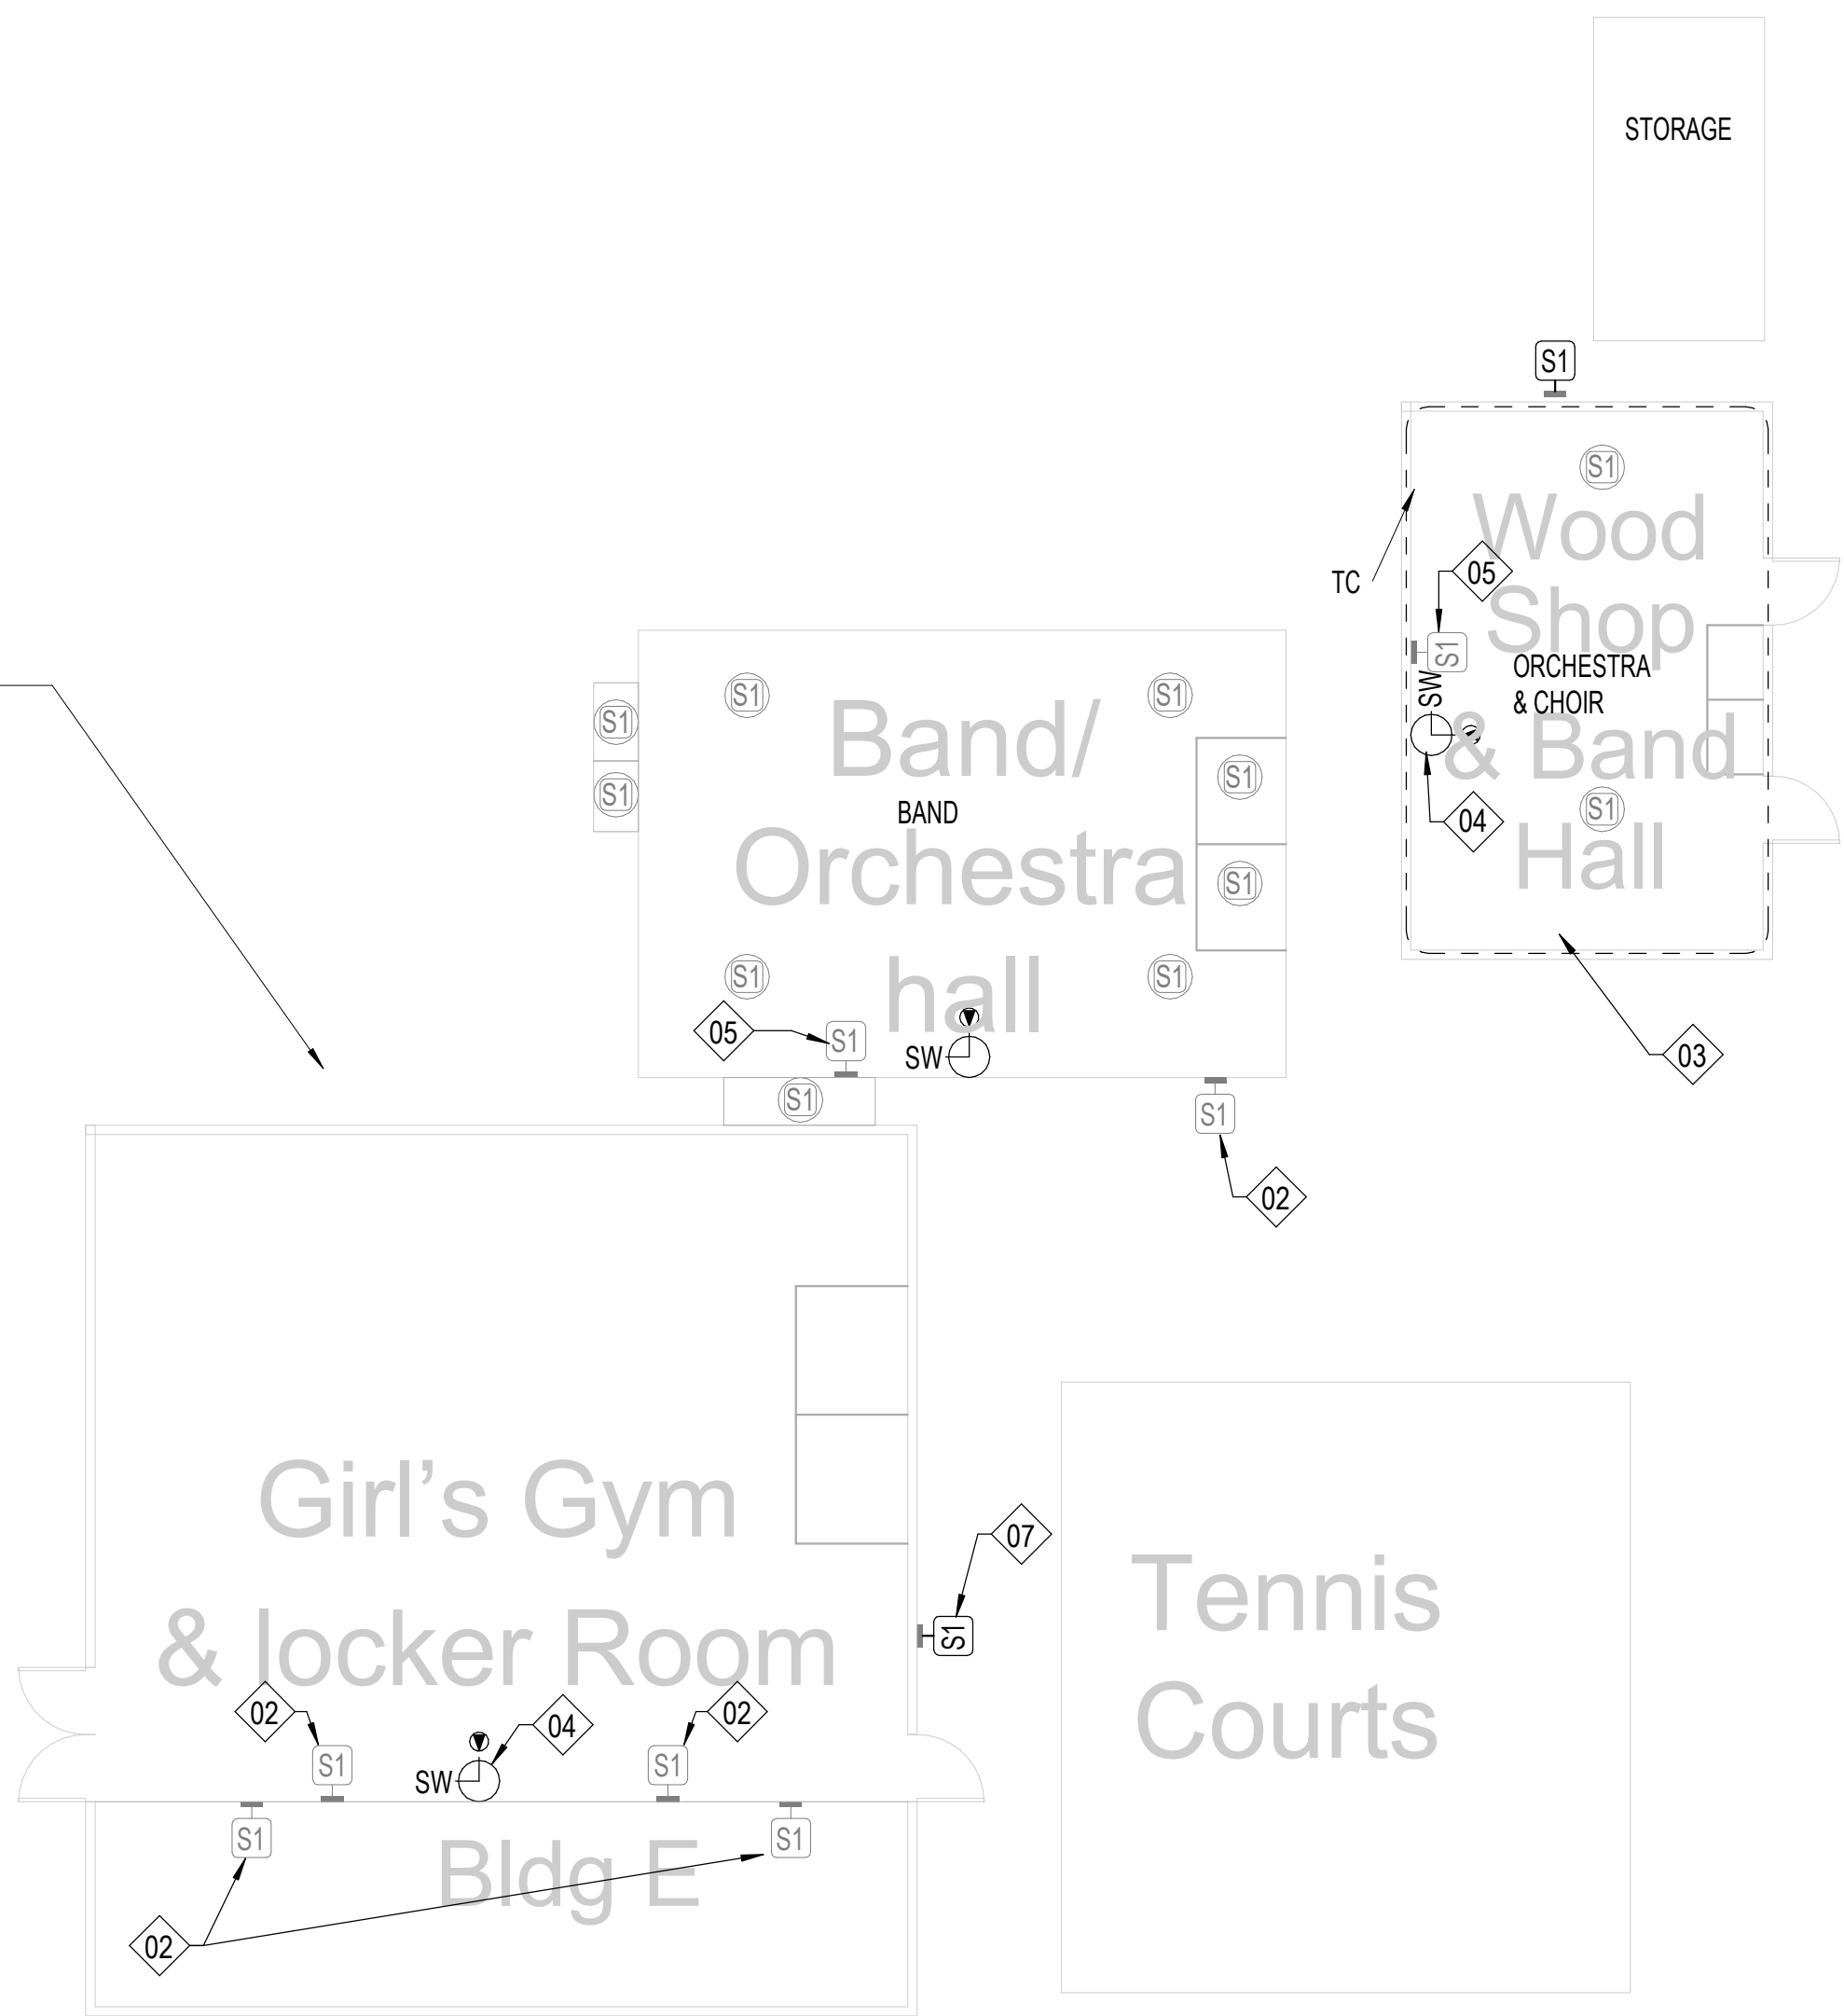

SHEET NOTES:

REFERENCE SHEET TG101 FOR ALL SYMBOLS AND PROJECT SPECIFIC NOTES.

EXISTING PAGING SPEAKERS (S1) ARE SHOWN IN HALF-TONE. CONTRACTOR SHALL REMOVE EXISTING PAGING SPEAKERS (S1) AND REPLACE WITH CEILING TILE OR BLANK COVER PLATE, UNO.

ALL CONDUITS SHALL BE 1" FOR ALL DEVICES UNLESS NOTED OTHERWISE ON THE TECHNOLOGY DRAWINGS.

IN AREAS WITH CONCRETE OR MASONRY WALLS, CONTRACTOR SHALL PROVIDE SURFACE RACEWAY SYSTEM.

IN AREAS WITH EXPOSED CEILINGS, CONTRACTOR SHALL INSTALL ALL CABLING IN CONDUIT. CONTRACTOR TO PERFORM PAINT FINISH AS COORDINATED WITH OWNER.

CONTRACTOR SHALL DEMOLISH ANY UNUSED CABLING BACK TO ITS ORIGIN AND DISPOSE.

CONTRACTOR SHALL REPLACE ALL EXISTING PTT BUTTONS PRESENT IN THE FACILITY WITH A BLANK COVER PLATE. CONTRACTOR SHALL LOCATE, DOCUMENT AND REMEDIATE IN THE SAME METHOD ANY PTT BUTTON NOT EXPLICITLY SHOWN IN THIS DRAWING SET.

CONTRACTOR IS RESPONSIBLE FOR PROVIDING LIFT FOR ALL HIGH CEILING AREAS (FINE ARTS, GYM, ETC.). CONTRACTOR SHALL ALSO BE REQUIRED TO PROVIDE FLOORING PROTECTION.

KEYNOTE LEGEND

(NOT ALL KEYNOTES MAY APPLY)

01. EXISTING, CONTRACTOR SHALL REPLACE WITH NEW DEVICE AND NEW CABLING. CEILING TILE MAY REMAIN IN PLACE UNLESS DAMAGED.

02. EXISTING, TO REMAIN. CONTRACTOR SHALL INSTALL BRIDGE FROM ANALOG SPEAKER TO IP HEAD END.

03. CONTRACTOR SHALL COMPLETELY REMOVE ALL ABANDONED ANALOG SPEAKER WIRING AND SUPPORTING TERMINAL BLOCKS FROM THE FACILITY. TERMINAL BLOCKS THAT SUPPORT OTHER EXISTING DEVICES SHALL REMAIN.

04. INSTALL PLASTIC 1/2" RACEWAY FOR PATCH CABLE TO TOP OF SURFACE MOUNTED CLOCK BACK BOX. TERMINATE DATA ABOVE CEILING.

05. EXISTING, CONTRACTOR SHALL REMOVE DEVICE, DEMOLISH CABLING BACK TO ITS ORIGIN, AND INSTALL NEW BLANK FACEPLATE.

06. INSTALL DATA IN ADJACENT OVERHEAD CEILING SPACE. PROVIDE 1" SLEEVE THROUGH CMU WALL TO BACK OF CLOCK DISPLAY.

07. SURFACE MOUNTED CONDUIT NEEDED FOR ALL NEW PAGING AND RELATED DEVICES.

08. PROVIDE 1" CONDUIT TO TOP OF SURFACE MOUNTED CLOCK BACK BOX FOR PATCH CABLE. DATA SHALL BE TERMINATED ABOVE CEILING.

09. INSTALL SURFACE MOUNTED RACEWAY FROM DEVICE BACK TO TECH CLOSET LOCATION.

10. CEILING SPEAKER IN CAN MOUNTED TO STRUCTURAL STEEL.

11. THIS IS A PLASTER CEILING, CONDUIT OR PLASTIC RACEWAY WILL NEED TO BE SECURED TO THE CEILING ITSELF.

12. SPEAKERS MOUNTED TO STRUCTURAL STEEL.

13. INSTALL SURFACE RACEWAY FOR ENTIRE PATH FROM TC TO DEVICE.

14. EXISTING SPEAKER BUILT FLUSH IN WALL. DO NOT REMOVE. INSTALL NEW DEVICE ADJACENT TO EXISTING. INSTALL DATA DROP IN ACCESSIBLE CEILING IN ADJACENT SPACE.

15. REMOVE EXISTING HORNS AND LEAVE MOUNTS INTACT, REMOVE EXISTING CABLING. INSTALL NEW DUAL SIDED DEVICE ADJACENT TO FORMER HORN LOCATION. INSTALL DATA IN ADJACENT CEILING SPACE.

16. REFERENCE DIV 27 FOR RACK INFORMATION AND ALLOWANCE REQUIREMENTS. FINAL LOCATIONS TO BE COORDINATED WITH OWNER PRIOR TO INSTALLATION.

17. NOT USED.

18. RECENTLY INSTALLED SPEAKER, REMOVE, PROTECT, AND REDEPLOY WHERE OTHER NEW ANALOG CEILING SPEAKERS ARE NEEDED.

19. J-BOX LARGER THAN 4X4" NEEDED HERE. PROVIDE ADDITIONAL SLACK FOR FUTURE RETERMINATIONS.

20. FIELD CONDITIONS MAY DIFFER FROM WHAT IS SHOWN. COORDINATE EXACT LOCATION WITH OWNER.

21. GYP CEILING. CONTRACTOR SHALL ACCOUNT FOR THREE (3) 24"x24" ACCESS PANEL LOCATIONS IN PRICING. VERIFY PATHWAYS ON SITE.

2 FLOOR PLAN - LONE STAR MS - SECOND FLOOR

1/8" = 1'-0"

1 FLOOR PLAN - LONE STAR MS - FIRST FLOOR

1/8" = 1'-0"

Description

Addendum 01

Date: 05/18/25

Revision: 1

SAN ANGELO ISD
PAGING UPGRADE
SAN ANGELO, TEXAS
D-SAN-1003-01

Project:




FLOOR PLAN - LONE STAR MS


Job No. D-SAN-1003-01
Drawn By: CV
Designed By: CV
Date: 04/29/2025
Sheet No. T134

Autodesk Docs: CRUX-San Angelo ISD Paging System Upgrade\B SAN-1003-01 SANSD ISD Paging Upgrade, TECH_02\HOSTED.rvt

1 CENTRAL ON OAKS GYM
1136 1/16" = 1'-0"

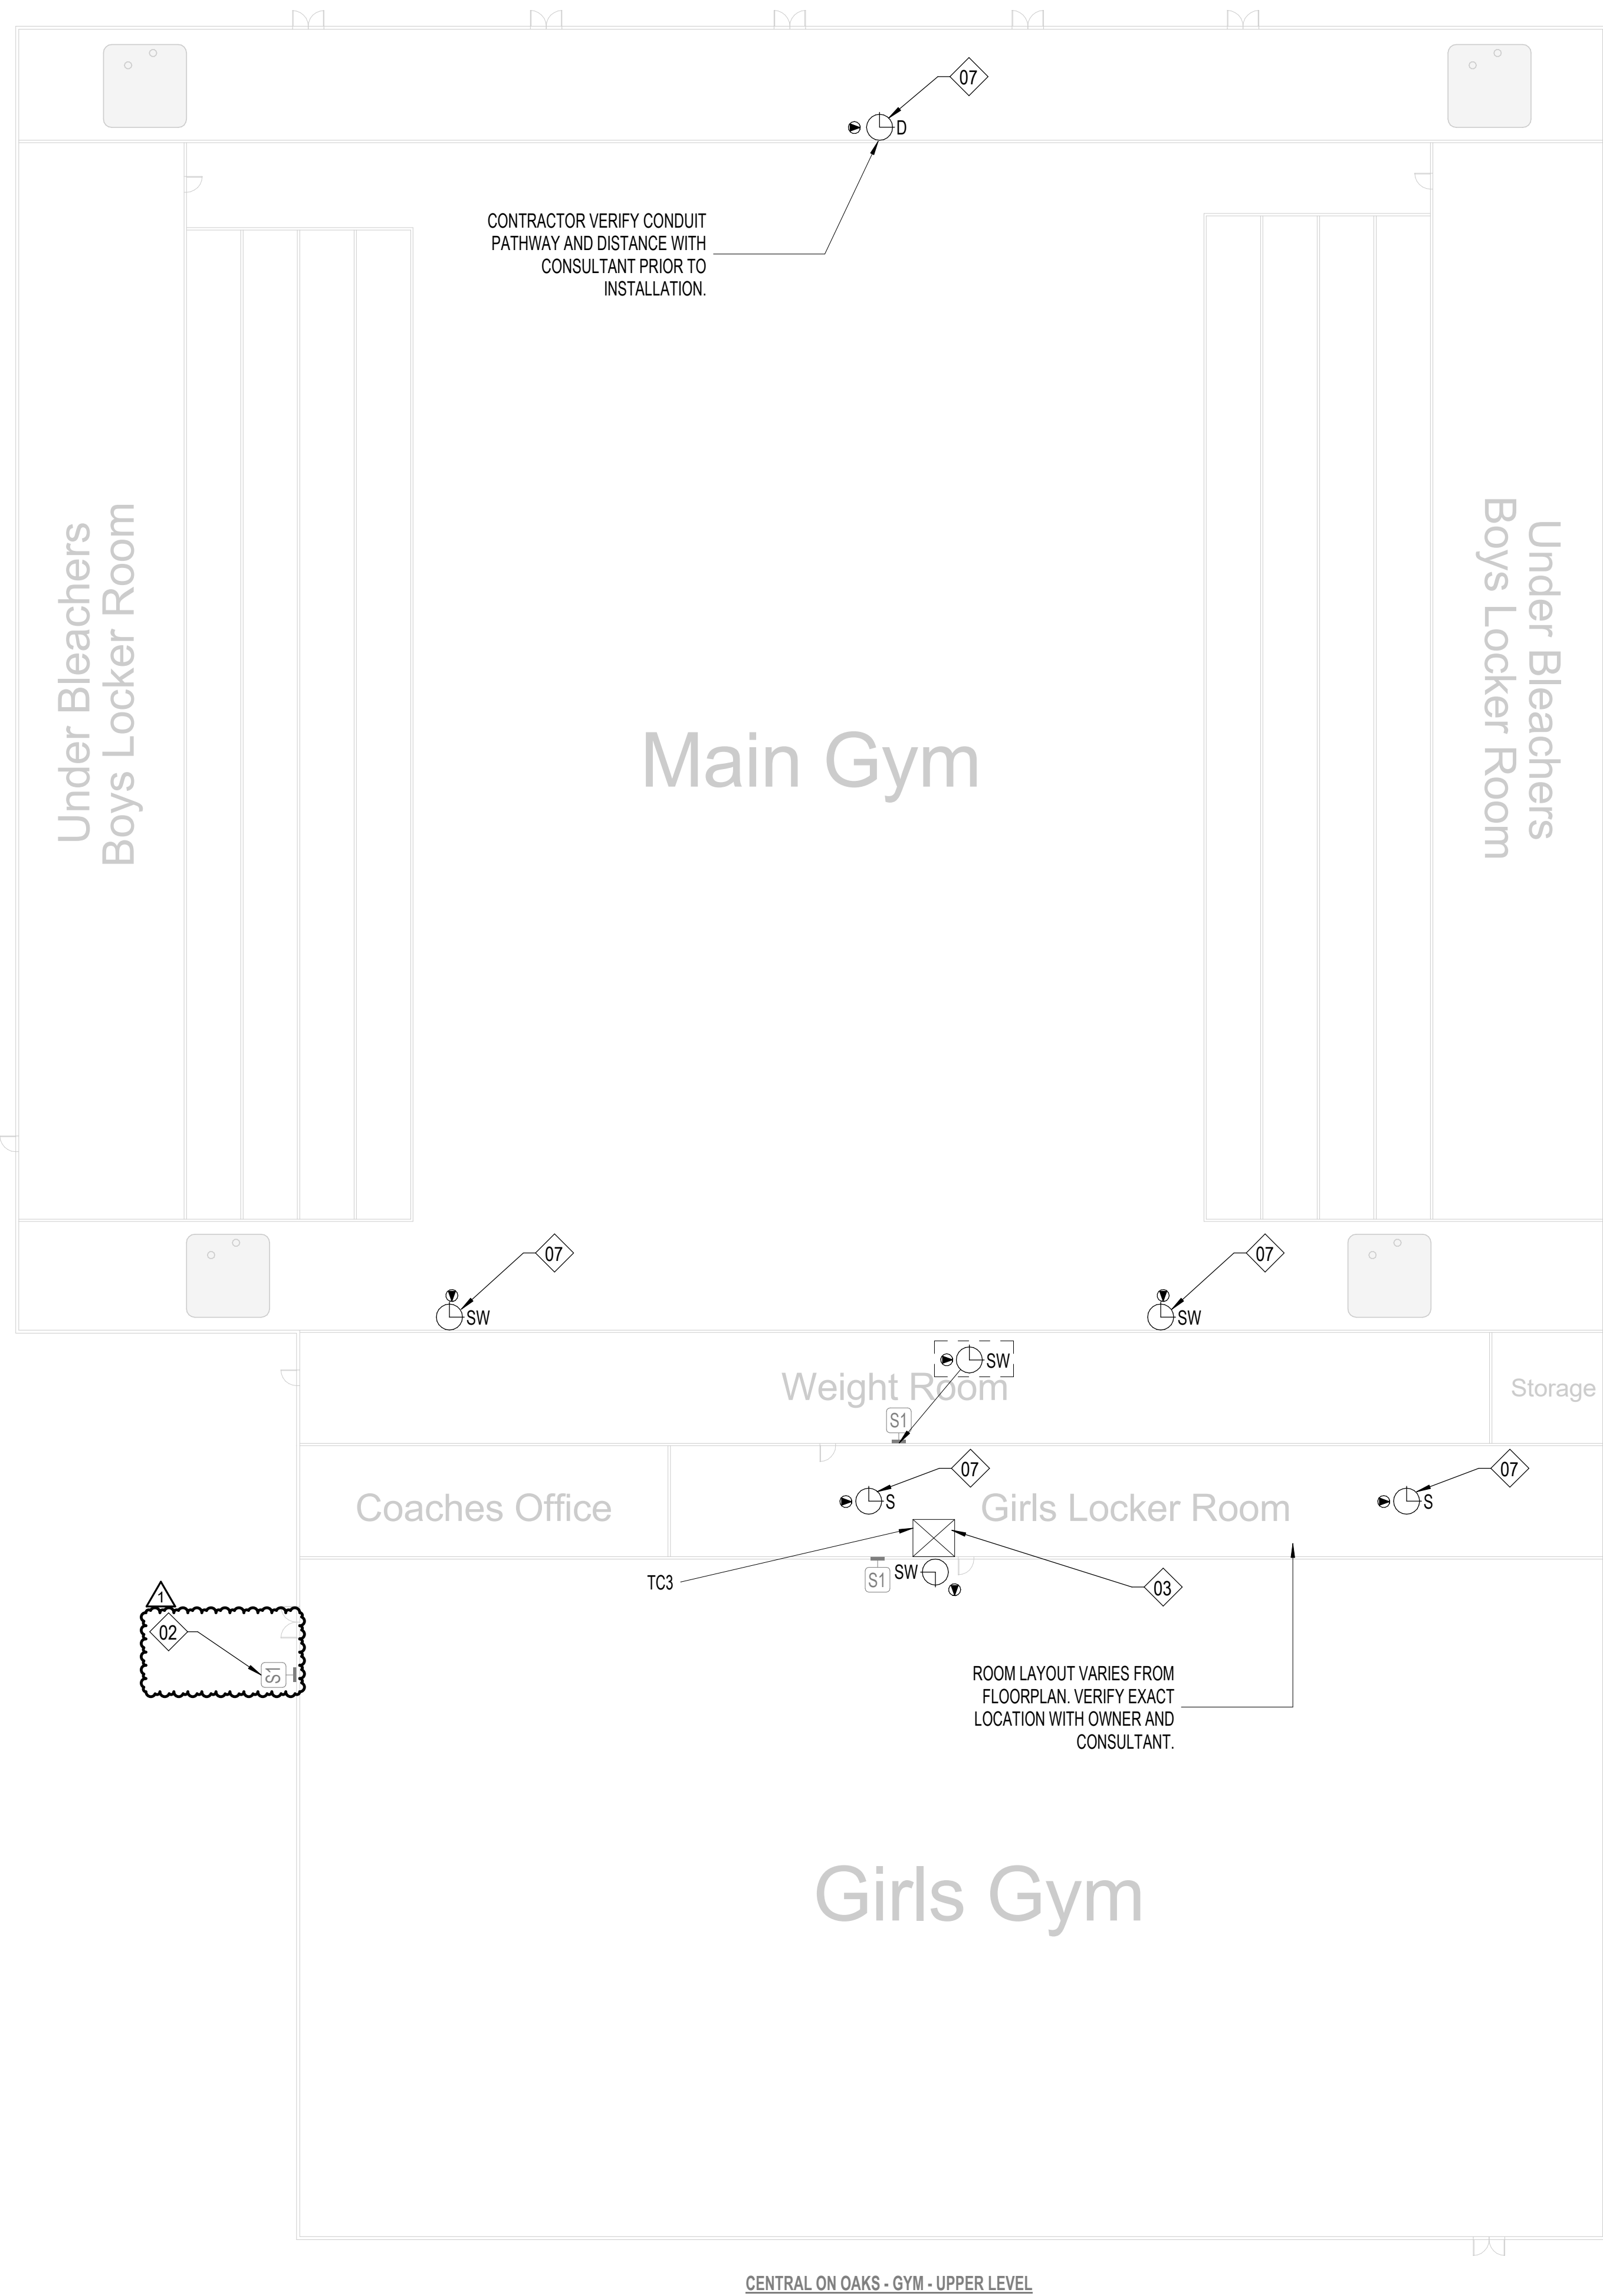

CENTRAL ON OAKS - GYM - UPPER LEVEL

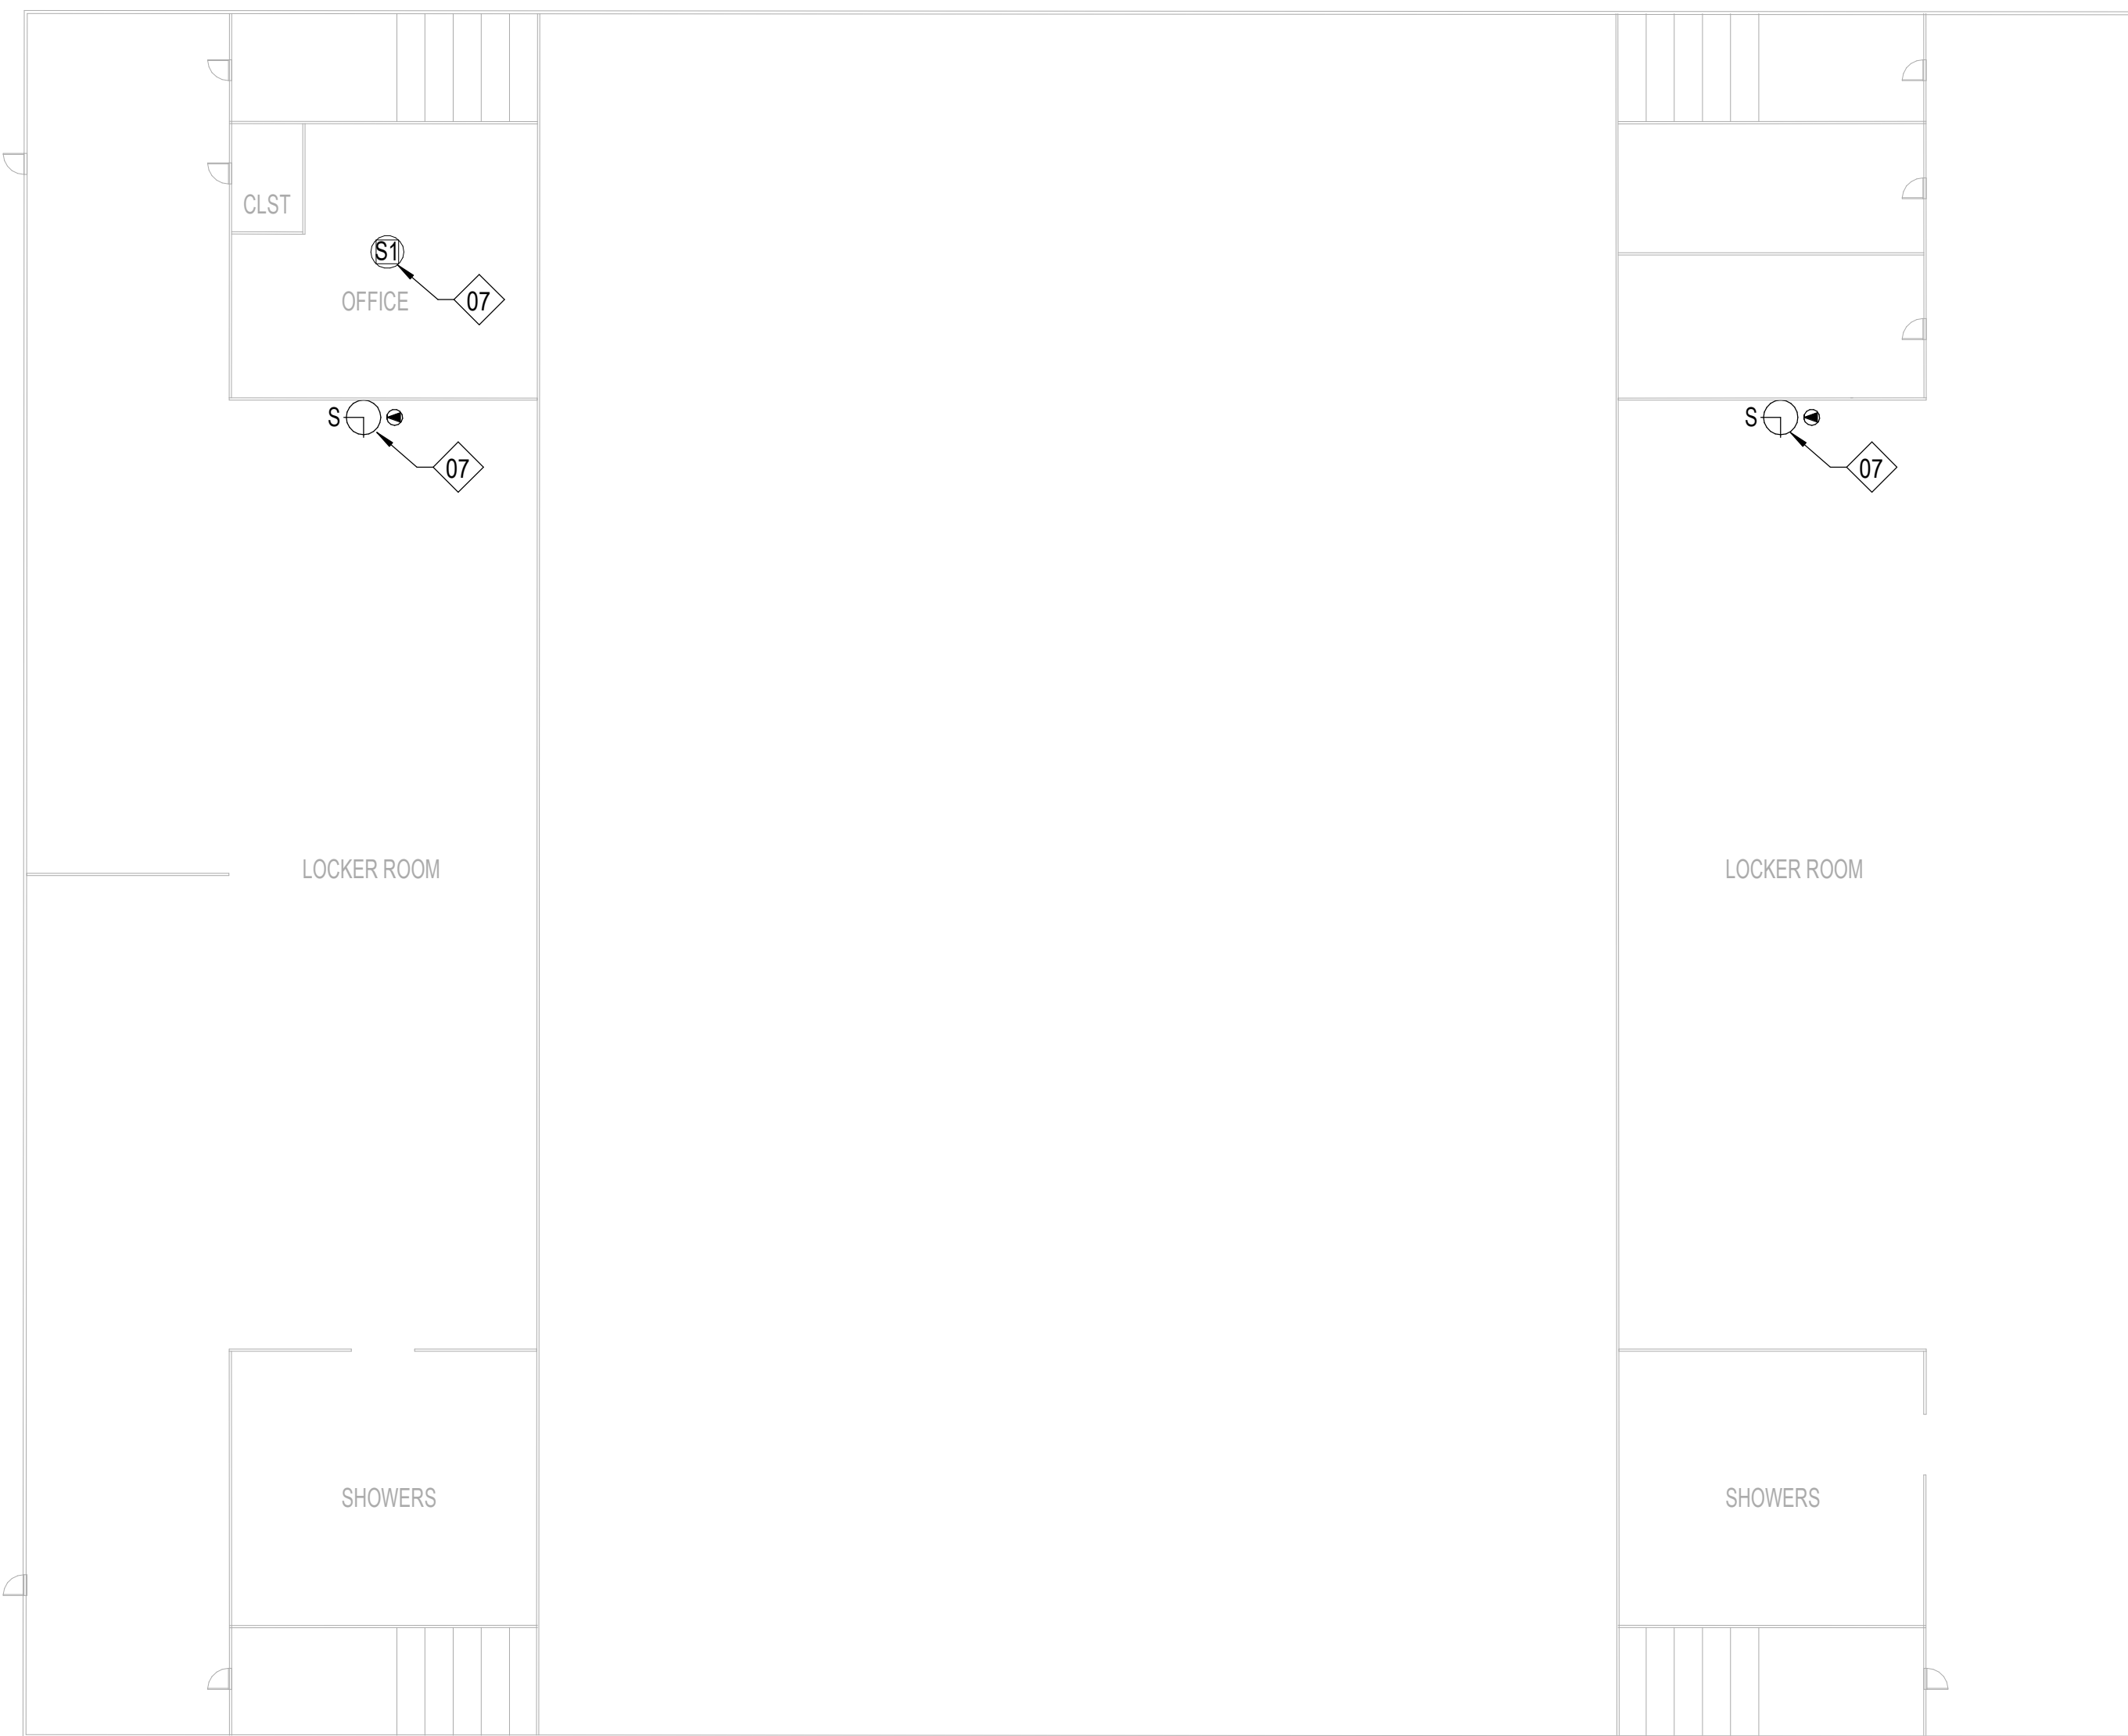

CENTRAL ON OAKS - GYM - LOWER LEVEL

SHEET NOTES:

REFERENCE SHEET TG101 FOR ALL SYMBOLS AND PROJECT SPECIFIC NOTES.

EXISTING PAGING SPEAKERS (S1) ARE SHOWN IN HALF-TONE. CONTRACTOR SHALL REMOVE EXISTING PAGING SPEAKERS (S1) AND REPLACE WITH CEILING TILE OR BLANK COVER PLATE, UNO.

ALL CONDUITS SHALL BE 1" FOR ALL DEVICES UNLESS NOTED OTHERWISE ON THE TECHNOLOGY DRAWINGS.

IN AREAS WITH CONCRETE OR MASONRY WALLS, CONTRACTOR SHALL PROVIDE SURFACE RACEWAY SYSTEM.

IN AREAS WITH EXPOSED CEILINGS, CONTRACTOR SHALL INSTALL ALL CABLING IN CONDUIT. CONTRACTOR TO PERFORM PAINT FINISH AS COORDINATED WITH OWNER.

CONTRACTOR SHALL DEMOLISH ANY UNUSED CABLING BACK TO ITS ORIGIN AND DISPOSE.

CONTRACTOR SHALL REPLACE ALL EXISTING PTT BUTTONS PRESENT IN THE FACILITY WITH A BLANK COVER PLATE. CONTRACTOR SHALL LOCATE, DOCUMENT AND REMEDIATE IN THE SAME METHOD ANY PTT BUTTON NOT EXPLICITLY SHOWN IN THIS DRAWING SET.

CONTRACTOR IS RESPONSIBLE FOR PROVIDING LIFT FOR ALL HIGH CEILING AREAS (FINE ARTS, GYMS, ETC.). CONTRACTOR SHALL ALSO BE REQUIRED TO PROVIDE FLOORING PROTECTION.

KEYNOTE LEGEND

(NOT ALL KEYNOTES MAY APPLY)

01. EXISTING, CONTRACTOR SHALL REPLACE WITH NEW DEVICE AND NEW CABLING. CEILING TILE MAY REMAIN IN PLACE UNLESS DAMAGED.

02. EXISTING, TO REMAIN. CONTRACTOR SHALL INSTALL BRIDGE FROM ANALOG SPEAKER TO IP HEAD END.

03. CONTRACTOR SHALL COMPLETELY REMOVE ALL ABANDONED ANALOG SPEAKER WIRING AND SUPPORTING TERMINAL BLOCKS FROM THE FACILITY. TERMINAL BLOCKS THAT SUPPORT OTHER EXISTING DEVICES SHALL REMAIN.

04. INSTALL PLASTIC 1/2" RACEWAY FOR PATCH CABLE TO TOP OF SURFACE MOUNTED CLOCK BACK BOX. TERMINATE DATA ABOVE CEILING.

05. EXISTING, CONTRACTOR SHALL REMOVE DEVICE, DEMOLISH CABLING BACK TO ITS ORIGIN, AND INSTALL NEW BLANK FACEPLATE.

06. INSTALL DATA IN ADJACENT OVERHEAD CEILING SPACE. PROVIDE 1" SLEEVE THROUGH CMU WALL TO BACK OF CLOCK DISPLAY.

07. SURFACE MOUNTED CONDUIT NEEDED FOR ALL NEW PAGING AND RELATED DEVICES.

08. PROVIDE 1" CONDUIT TO TOP OF SURFACE MOUNTED CLOCK BACK BOX FOR PATCH CABLE. DATA SHALL BE TERMINATED ABOVE CEILING.

09. INSTALL SURFACE MOUNTED RACEWAY FROM DEVICE BACK TO TECH CLOSET LOCATION.

10. CEILING SPEAKER IN CAN MOUNTED TO STRUCTURAL STEEL.

11. THIS IS A PLASTER CEILING, CONDUIT OR PLASTIC RACEWAY WILL NEED TO BE SECURED TO THE CEILING ITSELF.

12. SPEAKERS MOUNTED TO STRUCTURAL STEEL.

13. INSTALL SURFACE RACEWAY FOR ENTIRE PATH FROM TC TO DEVICE.

14. EXISTING SPEAKER BUILT FLUSH IN WALL. DO NOT REMOVE. INSTALL NEW DEVICE ADJACENT TO EXISTING. INSTALL DATA DROP IN ACCESSIBLE CEILING IN ADJACENT SPACE.

15. REMOVE EXISTING HORNS AND LEAVE MOUNTS INTACT, REMOVE EXISTING CABLING. INSTALL NEW DUAL SIDED DEVICE ADJACENT TO FORMER HORN LOCATION. INSTALL DATA IN ADJACENT CEILING SPACE.

16. REFERENCE DIV 27 FOR RACK INFORMATION AND ALLOWANCE REQUIREMENTS. FINAL LOCATIONS TO BE COORDINATED WITH OWNER PRIOR TO INSTALLATION.

17. NOT USED.

18. RECENTLY INSTALLED SPEAKER, REMOVE, PROTECT, AND REDEPLOY WHERE OTHER NEW ANALOG CEILING SPEAKERS ARE NEEDED.

19. J-BOX LARGER THAN 4X4" NEEDED HERE. PROVIDE ADDITIONAL SLACK FOR FUTURE RETERMINATIONS.

20. FIELD CONDITIONS MAY DIFFER FROM WHAT IS SHOWN. COORDINATE EXACT LOCATION WITH OWNER.

21. GYP CEILING. CONTRACTOR SHALL ACCOUNT FOR THREE (3) 24"X24" ACCESS PANEL LOCATIONS IN PRICING. VERIFY PATHWAYS ON SITE.

Description

Addendum 01

Date: 05/18/25

Revision: 1

Project:

SAN ANGELO ISD
PAGING UPGRADE
SAN ANGELO, TEXAS
D-SAN-1003-01



CRUX
TECHNOLOGY • SECURITY SOLUTIONS
800.665.6440
www.cruxsolutions.com

FLOOR PLAN - CENTRAL
ON OAKS (DAEP/PAYS)
GYM

VOLUME

Job No.
D-SAN-1003-01

Drawn By:
CV




Designed By:
CV

Date:
04/29/2025

Sheet No.

T136

Autodesk Docs\CRUX-San Angelo ISD Paging System Upgrade\B SAN-1003-01 SANSD ISD Paging Upgrade, TECH_02\HOSTED.rvt

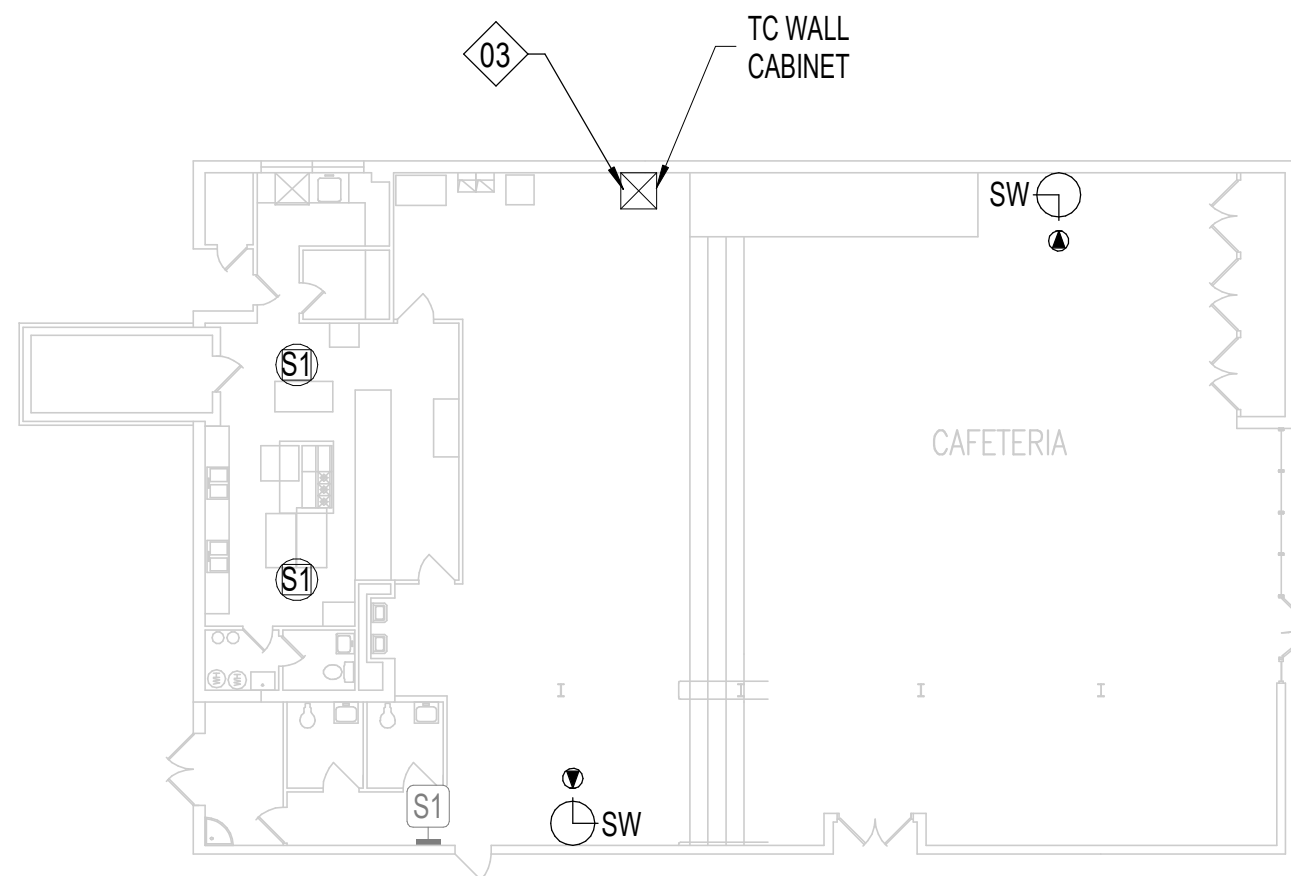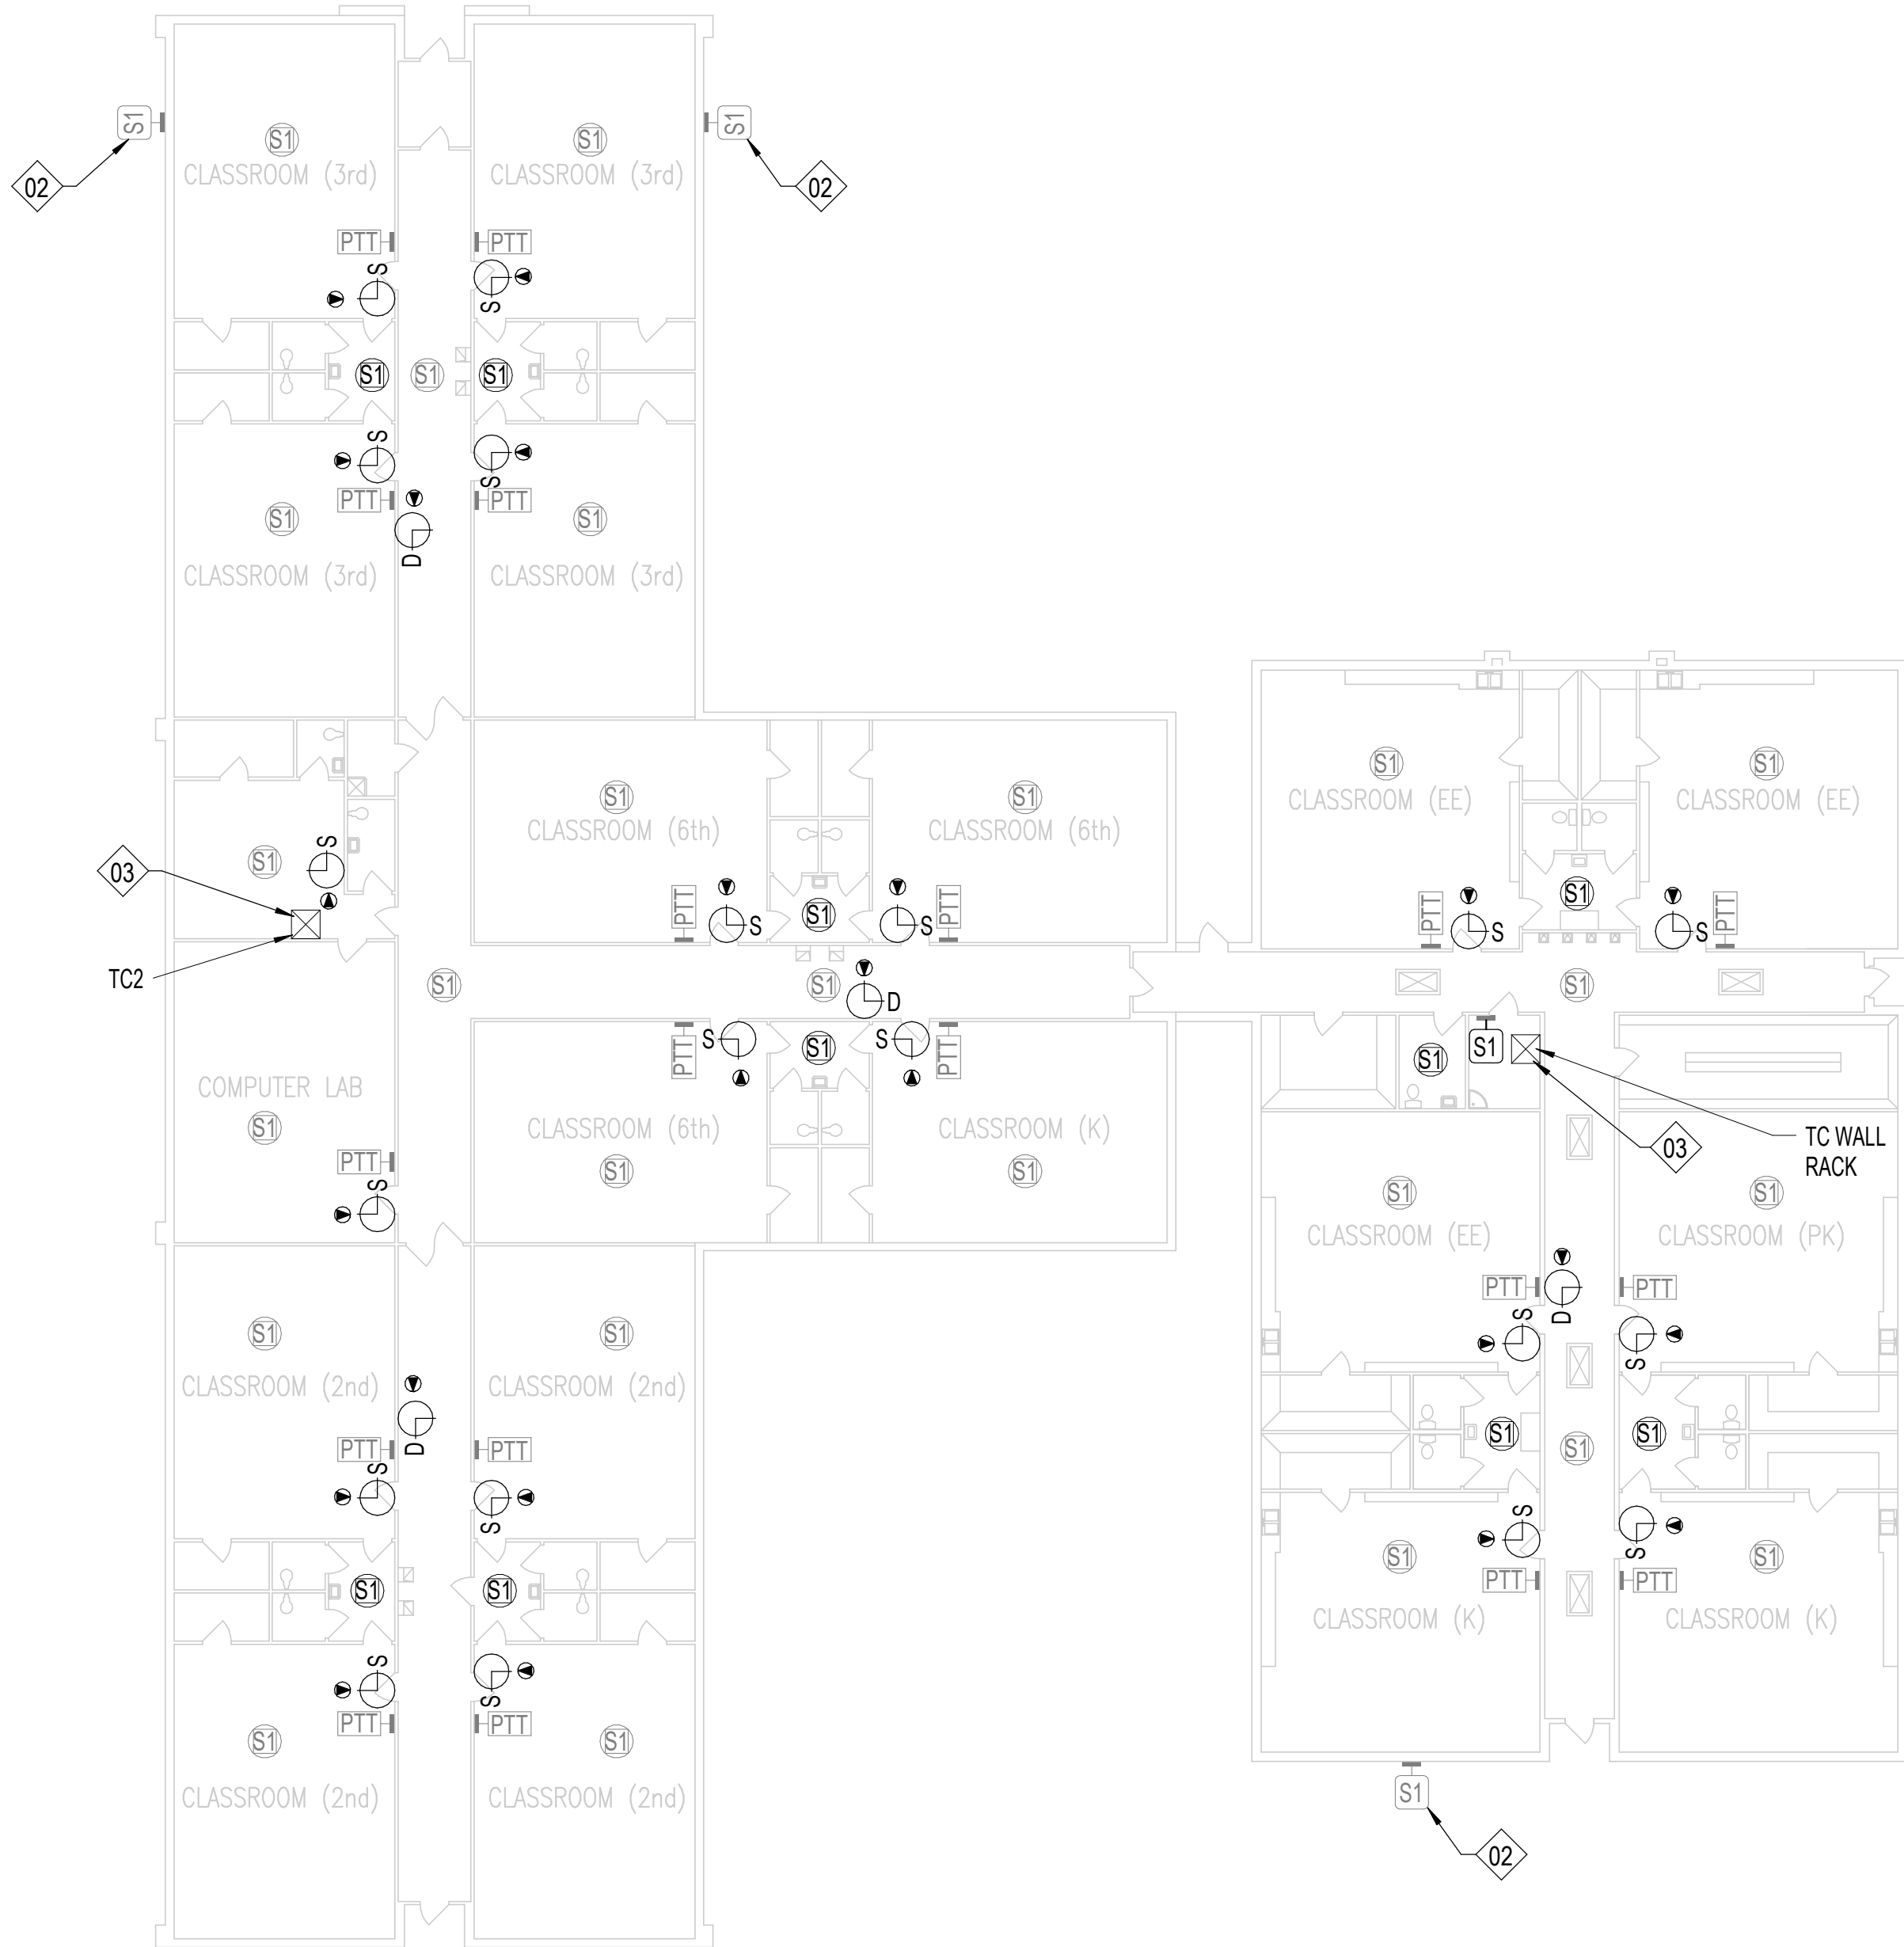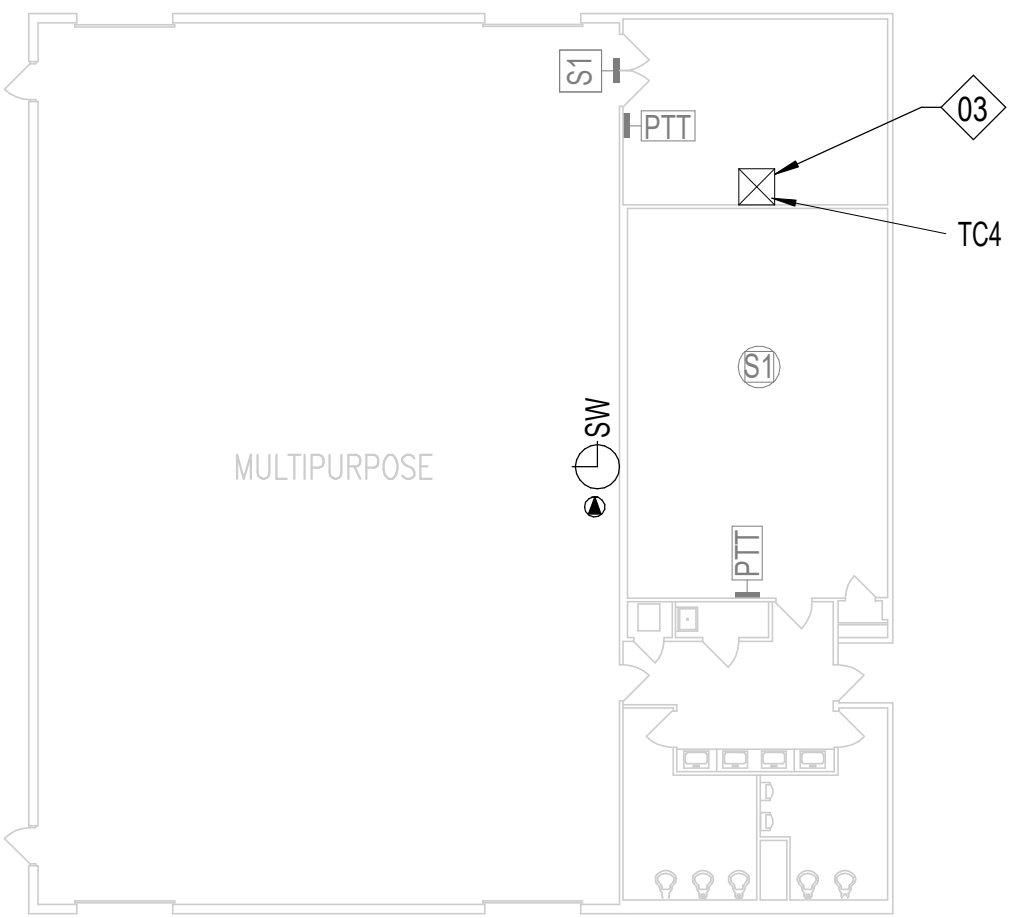

SHEET NOTES:

REFERENCE SHEET TG101 FOR ALL SYMBOLS AND PROJECT SPECIFIC NOTES.

EXISTING PAGING SPEAKERS (S1) ARE SHOWN IN HALF-TONE. CONTRACTOR SHALL REMOVE EXISTING PAGING SPEAKERS (S1) AND REPLACE WITH CEILING TILE OR BLANK COVER PLATE, UNO.

ALL CONDUITS SHALL BE 1" FOR ALL DEVICES UNLESS NOTED OTHERWISE ON THE TECHNOLOGY DRAWINGS.

IN AREAS WITH CONCRETE OR MASONRY WALLS, CONTRACTOR SHALL PROVIDE SURFACE RACEWAY SYSTEM.

IN AREAS WITH EXPOSED CEILINGS, CONTRACTOR SHALL INSTALL ALL CABLING IN CONDUIT. CONTRACTOR SHALL PAINT FINISH AS COORDINATED WITH OWNER.

CONTRACTOR SHALL DEMOLISH ANY UNUSED CABLING BACK TO ITS ORIGIN AND DISPOSE.

CONTRACTOR SHALL REPLACE ALL EXISTING PTT BUTTONS PRESENT IN THE FACILITY WITH A BLANK COVER PLATE. CONTRACTOR SHALL LOCATE, DOCUMENT AND REMEDIATE IN THE SAME METHOD ANY PTT BUTTON NOT EXPLICITLY SHOWN IN THIS DRAWING SET.

CONTRACTOR IS RESPONSIBLE FOR PROVIDING LIFT FOR ALL HIGH CEILING AREAS (FINE ARTS, GYM, ETC.). CONTRACTOR SHALL ALSO BE REQUIRED TO PROVIDE FLOORING PROTECTION.

KEYNOTE LEGEND

(NOT ALL KEYNOTES MAY APPLY.)

01. EXISTING, CONTRACTOR SHALL REPLACE WITH NEW DEVICE AND NEW CABLING. CEILING TILE MAY REMAIN IN PLACE UNLESS DAMAGED.
02. EXISTING, TO REMAIN. CONTRACTOR SHALL INSTALL BRIDGE FROM ANALOG SPEAKER TO IP HEAD END.
03. CONTRACTOR SHALL COMPLETELY REMOVE ALL ABANDONED ANALOG SPEAKER WIRING AND SUPPORTING TERMINAL BLOCKS FROM THE FACILITY. TERMINAL BLOCKS THAT SUPPORT OTHER EXISTING DEVICES SHALL REMAIN.
04. INSTALL PLASTIC 1/2" RACEWAY FOR PATCH CABLE TO TOP OF SURFACE MOUNTED CLOCK BACK BOX. TERMINATE DATA ABOVE CEILING.
05. EXISTING, CONTRACTOR SHALL REMOVE DEVICE, DEMOLISH CABLING BACK TO ITS ORIGIN, AND INSTALL NEW BLANK FACEPLATE.
06. INSTALL DATA IN ADJACENT OVERHEAD CEILING SPACE. PROVIDE 1" SLEEVE THROUGH CMU WALL TO BACK OF CLOCK DISPLAY.
07. SURFACE MOUNTED CONDUIT NEEDED FOR ALL NEW PAGING AND RELATED DEVICES.
08. PROVIDE 1" CONDUIT TO TOP OF SURFACE MOUNTED CLOCK BACK BOX FOR PATCH CABLE. DATA SHALL BE TERMINATED ABOVE CEILING.
09. INSTALL SURFACE MOUNTED RACEWAY FROM DEVICE BACK TO TECH CLOSET LOCATION.
10. CEILING SPEAKER IN CAN MOUNTED TO STRUCTURAL STEEL.
11. THIS IS A PLASTER CEILING, CONDUIT OR PLASTIC RACEWAY WILL NEED TO BE SECURED TO THE CEILING ITSELF.
12. SPEAKERS MOUNTED TO STRUCTURAL STEEL.
13. INSTALL SURFACE RACEWAY FOR ENTIRE PATH FROM TC TO DEVICE.
14. EXISTING SPEAKER BUILT FLUSH IN WALL. DO NOT REMOVE. INSTALL NEW DEVICE ADJACENT TO EXISTING. INSTALL DATA DROP IN ACCESSIBLE CEILING IN ADJACENT SPACE.
15. REMOVE EXISTING HORNS AND LEAVE MOUNTS INTACT, REMOVE EXISTING CABLING. INSTALL NEW DUAL SIDED DEVICE ADJACENT TO FORMER HORN LOCATION. INSTALL DATA IN ADJACENT CEILING SPACE.
16. REFERENCE DIV 27 FOR RACK INFORMATION AND ALLOWANCE REQUIREMENTS. FINAL LOCATIONS TO BE COORDINATED WITH OWNER PRIOR TO INSTALLATION.
17. NOT USED.
18. RECENTLY INSTALLED SPEAKER, REMOVE, PROTECT, AND REDEPLOY WHERE OTHER NEW ANALOG CEILING SPEAKERS ARE NEEDED.
19. J-BOX LARGER THAN 4X4" NEEDED HERE. PROVIDE ADDITIONAL SLACK FOR FUTURE RETERMINATIONS.
20. FIELD CONDITIONS MAY DIFFER FROM WHAT IS SHOWN. COORDINATE EXACT LOCATION WITH OWNER.
21. GYP CEILING. CONTRACTOR SHALL ACCOUNT FOR THREE (3) 24"X24" ACCESS PANEL LOCATIONS IN PRICING. VERIFY PATHWAYS ON SITE.

1 FIRST FLOOR - AUSTIN PROFESSIONAL LEARNING (PL) - ADD ALTERNATE 1
T137 1/16" = 1'-0"

Description

Date:

Revision:

SAN ANGELO ISD
PAGING UPGRADE
SAN ANGELO, TEXAS
D-SAN-1003-01





Project:



FLOOR PLAN - AUSTIN
PROFESSIONAL LEARNING
(PL)

VOLUME
Job. No.
D-SAN-1003-01
Drawn By:
OG
Designed By:
OG
Date:
04/29/2026
Sheet No.
T137

Autodesk Docs\CRUX-San Angelo ISD Paging System Upgrade\B SAN-1003-01 SANSD ISD Paging Upgrade, TECH, 02\HOSTED.rvt

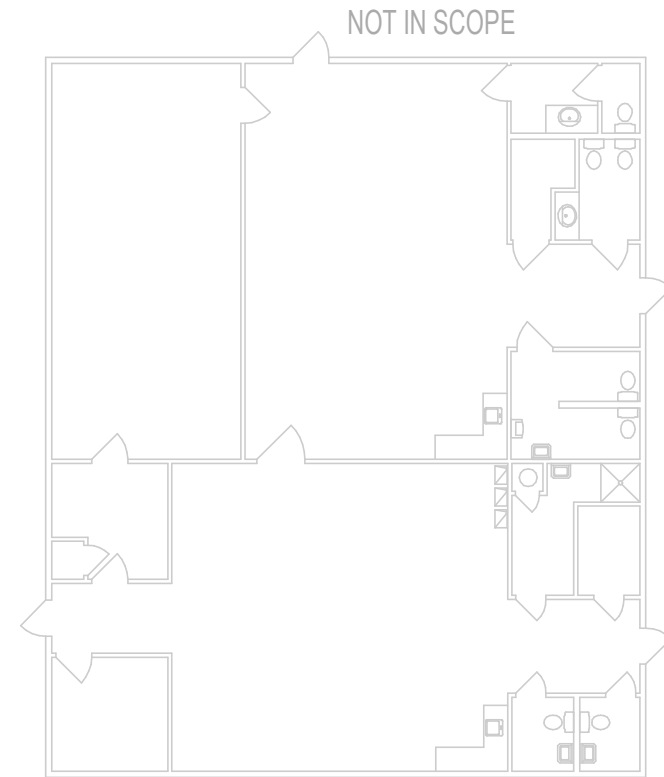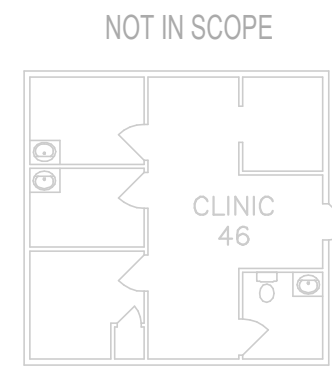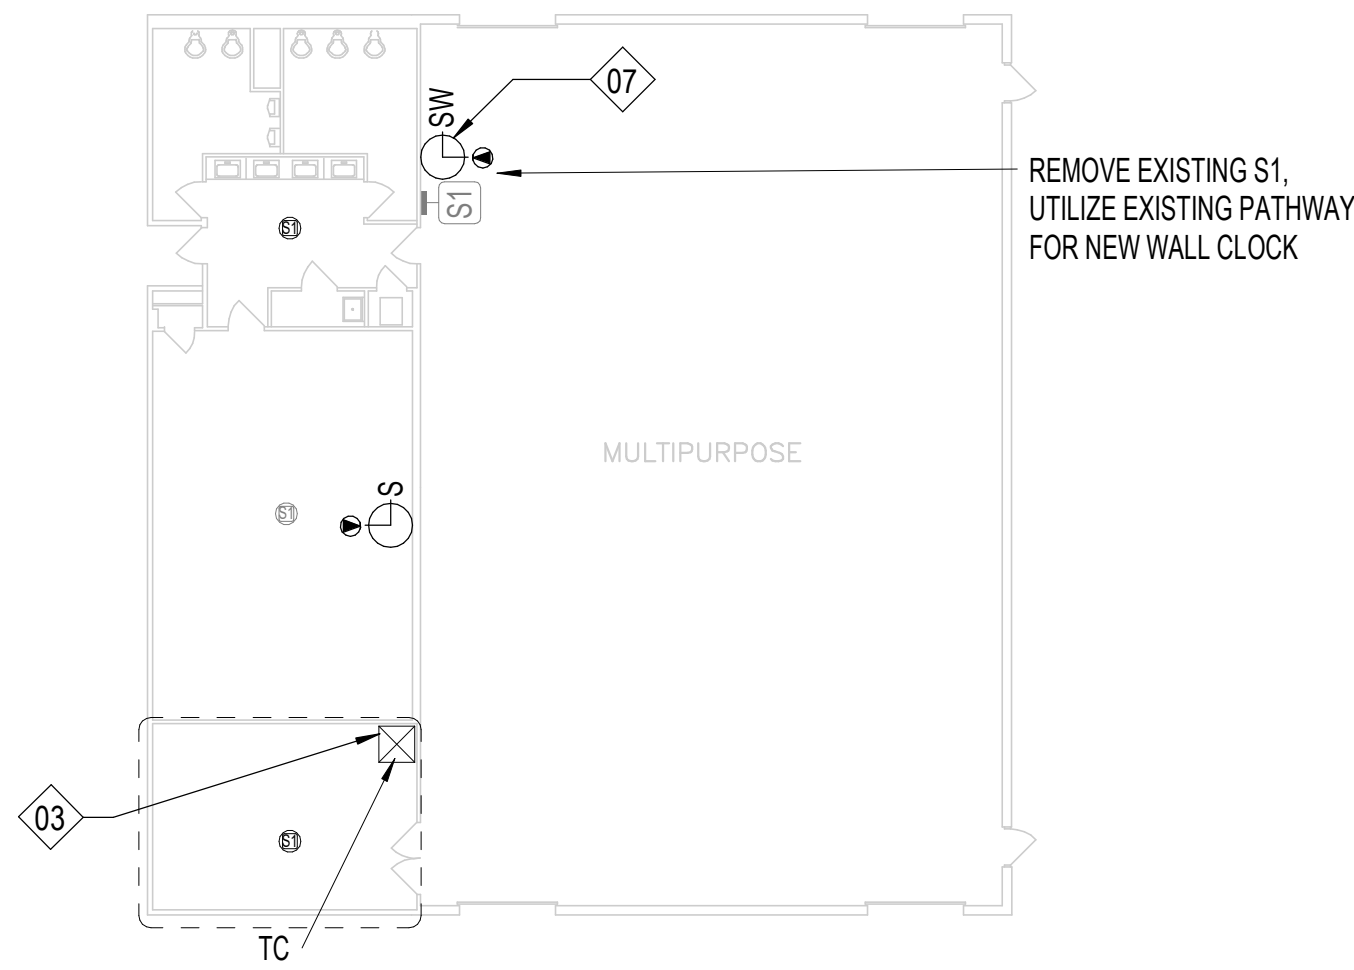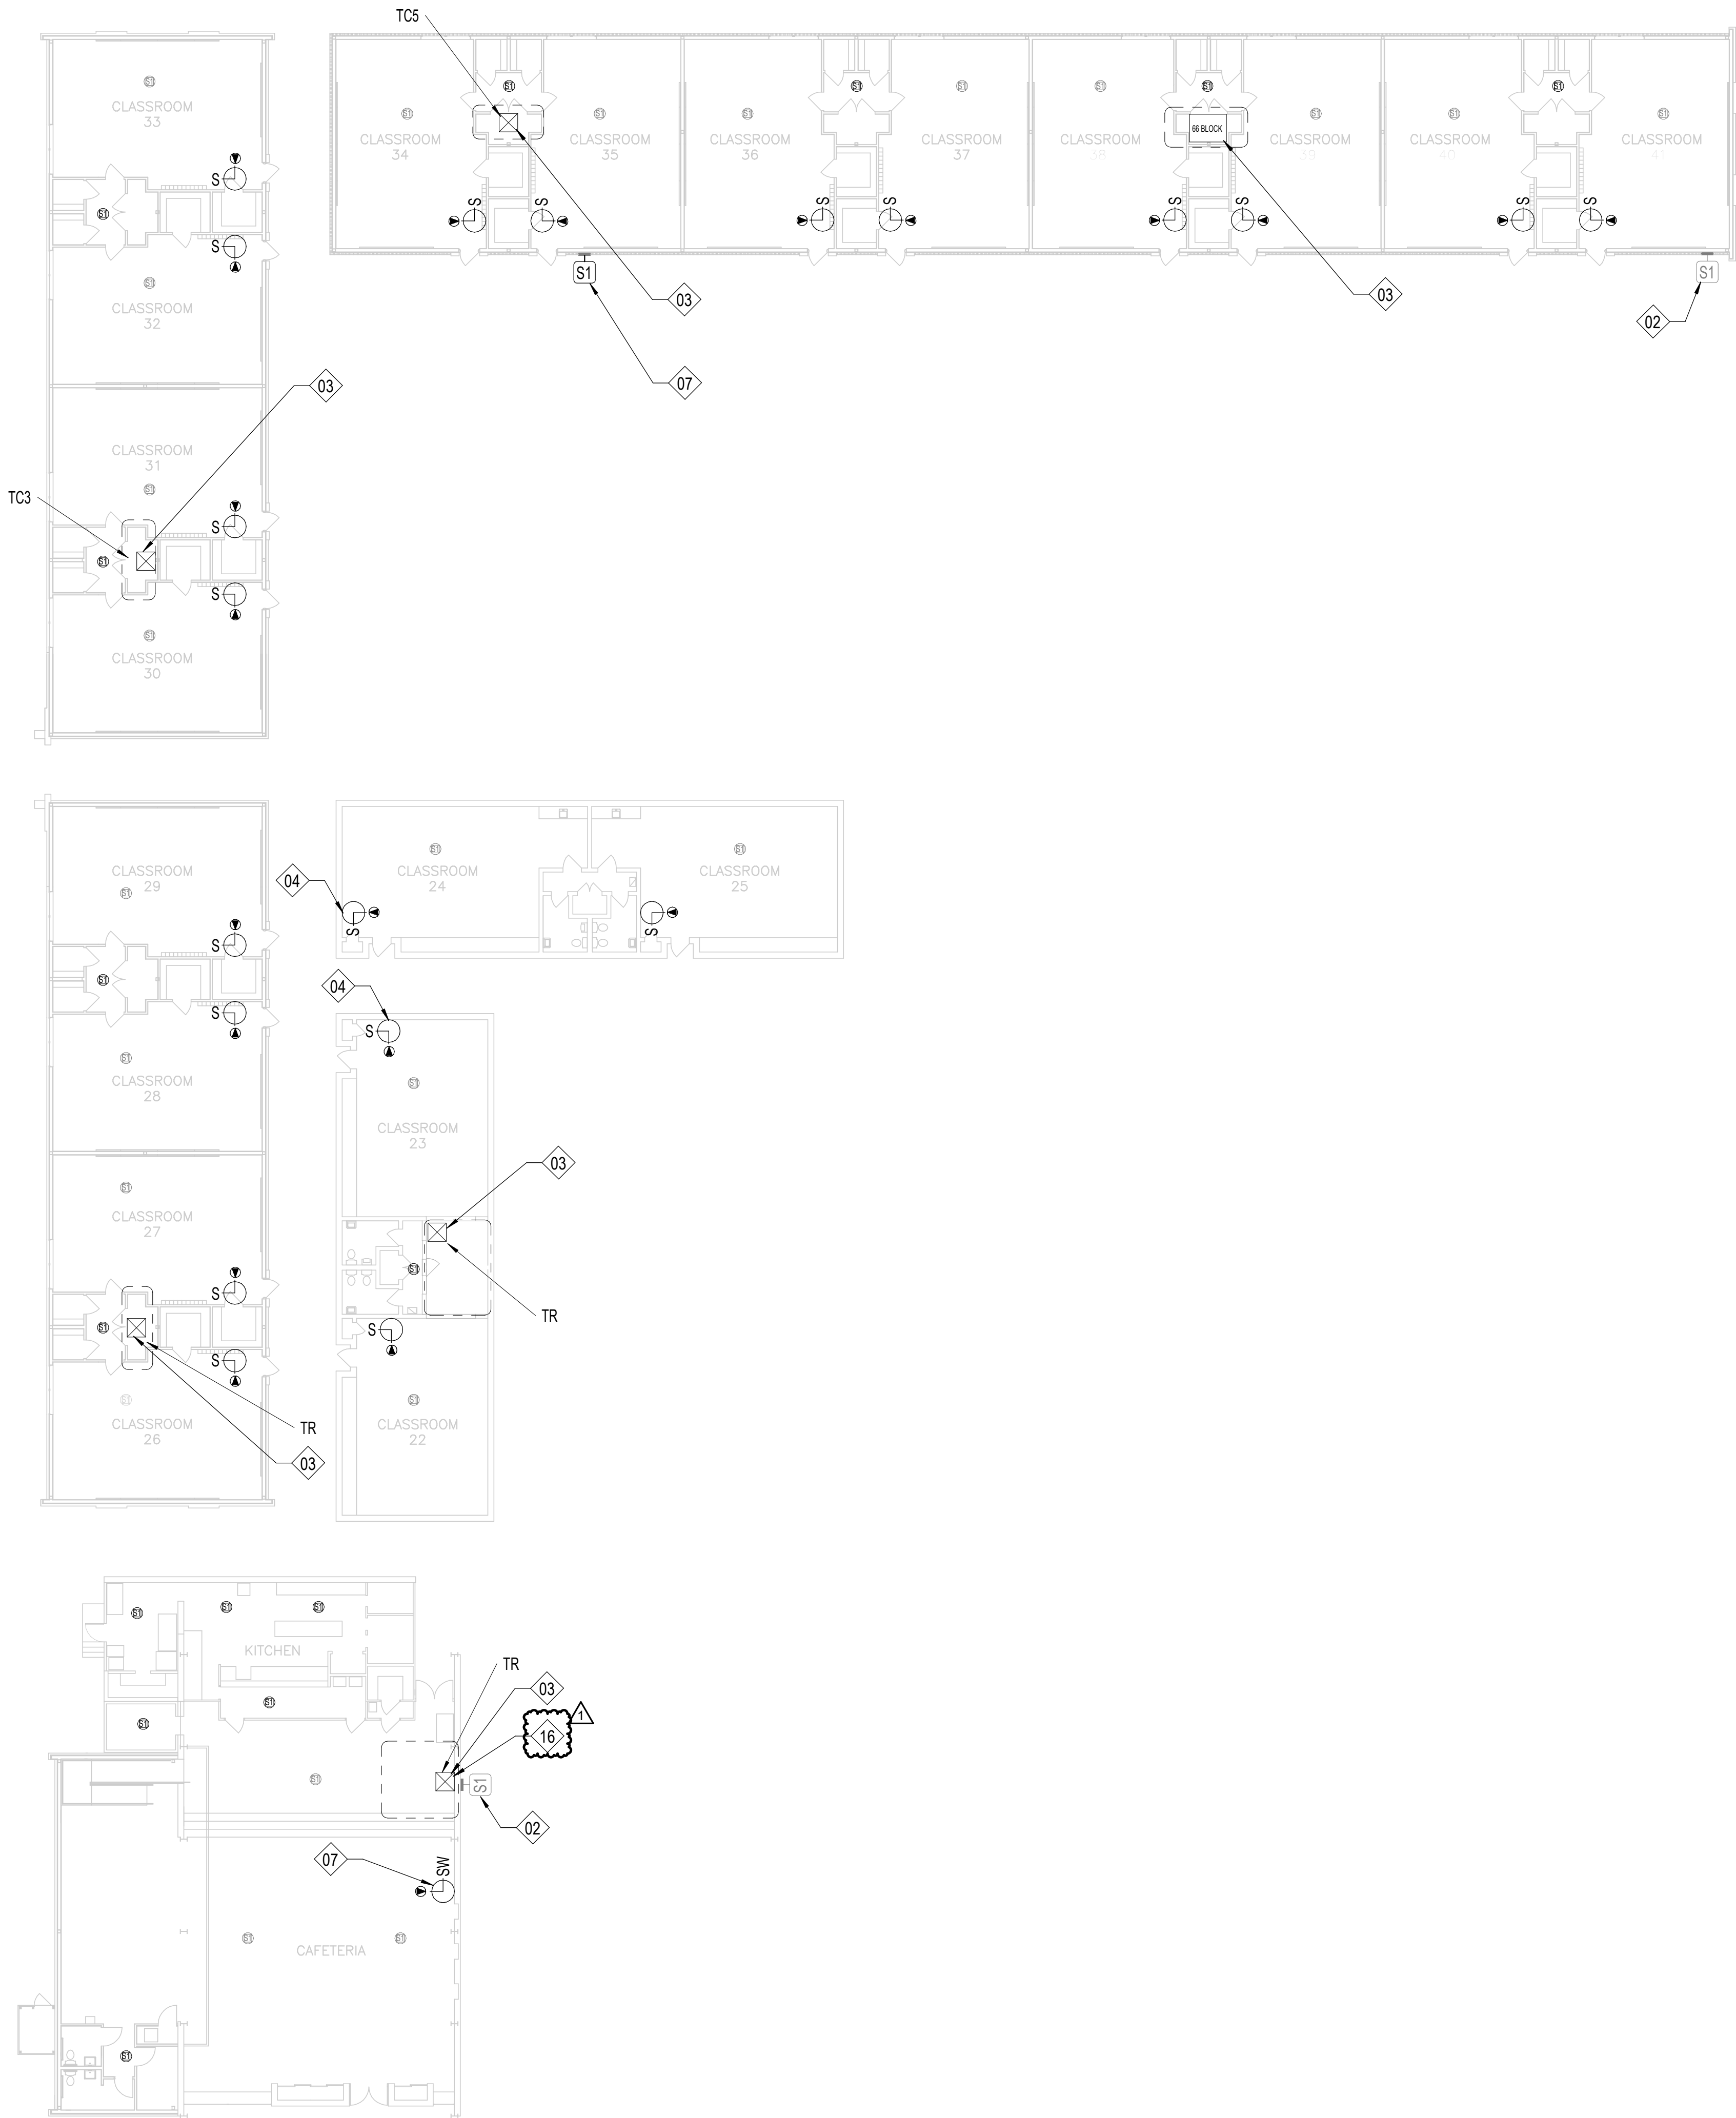

SHEET NOTES:

REFERENCE SHEET TG101 FOR ALL SYMBOLS AND PROJECT SPECIFIC NOTES.

EXISTING PAGING SPEAKERS (S1) ARE SHOWN IN HALF-TONE. CONTRACTOR SHALL REMOVE EXISTING PAGING SPEAKERS (S1) AND REPLACE WITH CEILING TILE OR BLANK COVER PLATE, UNLESS NOTED OTHERWISE.

ALL CONDUITS SHALL BE 1" FOR ALL DEVICES UNLESS NOTED OTHERWISE ON THE TECHNOLOGY DRAWINGS.

IN AREAS WITH CONCRETE OR MASONRY WALLS, CONTRACTOR SHALL PROVIDE SURFACE RACEWAY SYSTEM.

IN AREAS WITH EXPOSED CEILINGS, CONTRACTOR SHALL INSTALL ALL CABLING IN CONDUIT. CONTRACTOR TO PERFORM PAINT FINISH AS COORDINATED WITH OWNER.

CONTRACTOR SHALL DEMOLISH ANY UNUSED CABLING BACK TO ITS ORIGIN AND DISPOSE.

CONTRACTOR SHALL REPLACE ALL EXISTING PTT BUTTONS PRESENT IN THE FACILITY WITH A BLANK COVER PLATE. CONTRACTOR SHALL LOCATE, DOCUMENT AND REMEDIATE IN THE SAME METHOD ANY PTT BUTTON NOT EXPLICITLY SHOWN IN THIS DRAWING SET.

CONTRACTOR IS RESPONSIBLE FOR PROVIDING LIFT FOR ALL HIGH CEILING AREAS (FINE ARTS, GYM, ETC.). CONTRACTOR SHALL ALSO BE REQUIRED TO PROVIDE FLOORING PROTECTION.

KEYNOTE LEGEND

(NOT ALL KEYNOTES MAY APPLY)

01. EXISTING, CONTRACTOR SHALL REPLACE WITH NEW DEVICE AND NEW CABLING. CEILING TILE MAY REMAIN IN PLACE UNLESS DAMAGED.
02. EXISTING, TO REMAIN. CONTRACTOR SHALL INSTALL BRIDGE FROM ANALOG SPEAKER TO IP HEAD END.
03. CONTRACTOR SHALL COMPLETELY REMOVE ALL ABANDONED ANALOG SPEAKER WIRING AND SUPPORTING TERMINAL BLOCKS FROM THE FACILITY. TERMINAL BLOCKS THAT SUPPORT OTHER EXISTING DEVICES SHALL REMAIN.
04. INSTALL PLASTIC 1/2" RACEWAY FOR PATCH CABLE TO TOP OF SURFACE MOUNTED CLOCK BACK BOX. TERMINATE DATA ABOVE CEILING.
05. EXISTING, CONTRACTOR SHALL REMOVE DEVICE, DEMOLISH CABLING BACK TO ITS ORIGIN, AND INSTALL NEW BLANK FACEPLATE.
06. INSTALL DATA IN ADJACENT OVERHEAD CEILING SPACE. PROVIDE 1" SLEEVE THROUGH CMU WALL TO BACK OF CLOCK DISPLAY.
07. SURFACE MOUNTED CONDUIT NEEDED FOR ALL NEW PAGING AND RELATED DEVICES.
08. PROVIDE 1" CONDUIT TO TOP OF SURFACE MOUNTED CLOCK BACK BOX FOR PATCH CABLE. DATA SHALL BE TERMINATED ABOVE CEILING.
09. INSTALL SURFACE MOUNTED RACEWAY FROM DEVICE BACK TO TECH CLOSET LOCATION.
10. CEILING SPEAKER IN CAN MOUNTED TO STRUCTURAL STEEL.
11. THIS IS A PLASTER CEILING, CONDUIT OR PLASTIC RACEWAY WILL NEED TO BE SECURED TO THE CEILING ITSELF.
12. SPEAKERS MOUNTED TO STRUCTURAL STEEL.
13. INSTALL SURFACE RACEWAY FOR ENTIRE PATH FROM TC TO DEVICE.
14. EXISTING SPEAKER BUILT FLUSH IN WALL. DO NOT REMOVE. INSTALL NEW DEVICE ADJACENT TO EXISTING. INSTALL DATA DROP IN ACCESSIBLE CEILING IN ADJACENT SPACE.
15. REMOVE EXISTING HORNS AND LEAVE MOUNTS INTACT, REMOVE EXISTING CABLING. INSTALL NEW DUAL SIDED DEVICE ADJACENT TO FORMER HORN LOCATION. INSTALL DATA IN ADJACENT CEILING SPACE.
16. REFERENCE DIV 27 FOR RACK INFORMATION AND ALLOWANCE REQUIREMENTS. FINAL LOCATIONS TO BE COORDINATED WITH OWNER PRIOR TO INSTALLATION.
17. NOT USED.
18. RECENTLY INSTALLED SPEAKER, REMOVE, PROTECT, AND REDEPLOY WHERE OTHER NEW ANALOG CEILING SPEAKERS ARE NEEDED.
19. J-BOX LARGER THAN 4X4" NEEDED HERE. PROVIDE ADDITIONAL SLACK FOR FUTURE RETERMINATIONS.
20. FIELD CONDITIONS MAY DIFFER FROM WHAT IS SHOWN. COORDINATE EXACT LOCATION WITH OWNER.
21. GYP CEILING. CONTRACTOR SHALL ACCOUNT FOR THREE (3) 24"X24" ACCESS PANEL LOCATIONS IN PRICING. VERIFY PATHWAYS ON SITE.

1	FLOOR PLAN - SAN JACINTO ES	ADD ALTERNATE #2
T138	1/16" = 1'-0"	

Description

Addendum 01

Date: 05/18/25

Revision: 1

Project:

SAN ANGELO ISD
PAGING UPGRADE
SAN ANGELO, TEXAS
D-SAN-1003-01






FLOOR PLAN - SAN JACINTO ES

Job No. D-SAN-1003-01	Sheet No.
Drawn By: CV	T138
Designed By: CV	
Date: 04/29/2025	

Autocad Docs\CRUX-San Angelo ISD Paging System Upgrade\0-SAN-1003-01 SAN-SD ISD Paging Upgrade TECH 02(HOSTED).rvt

1 TYPICAL CLOCK MOUNTING DETAILS
1301 NTS

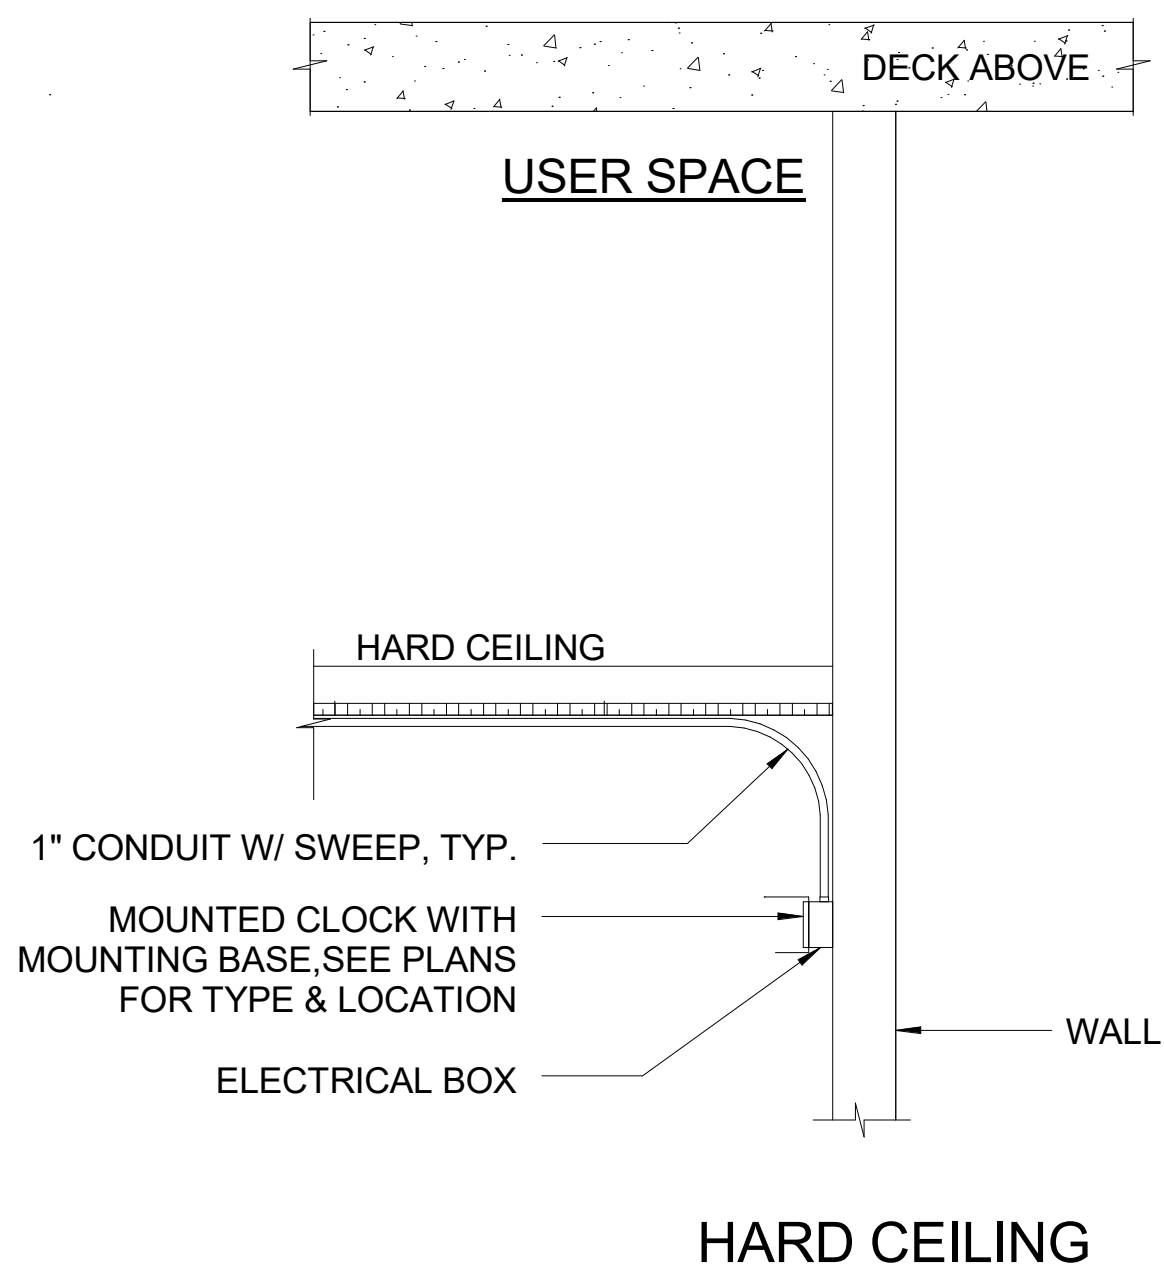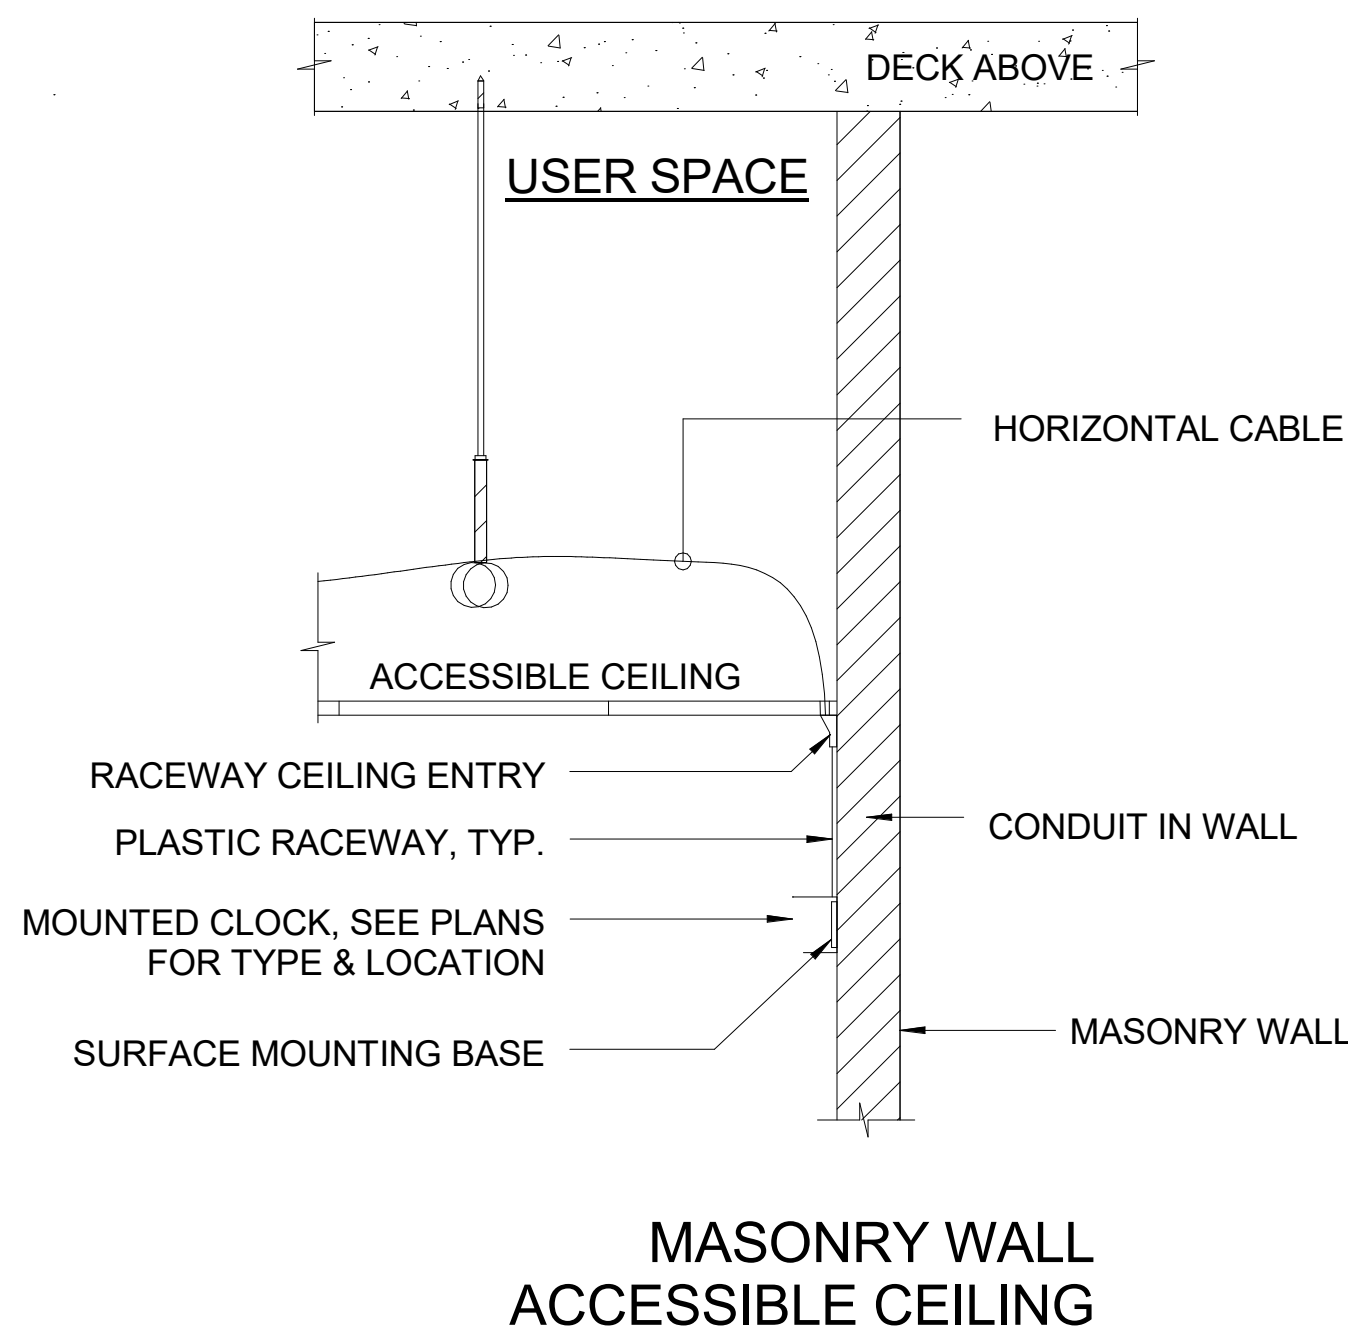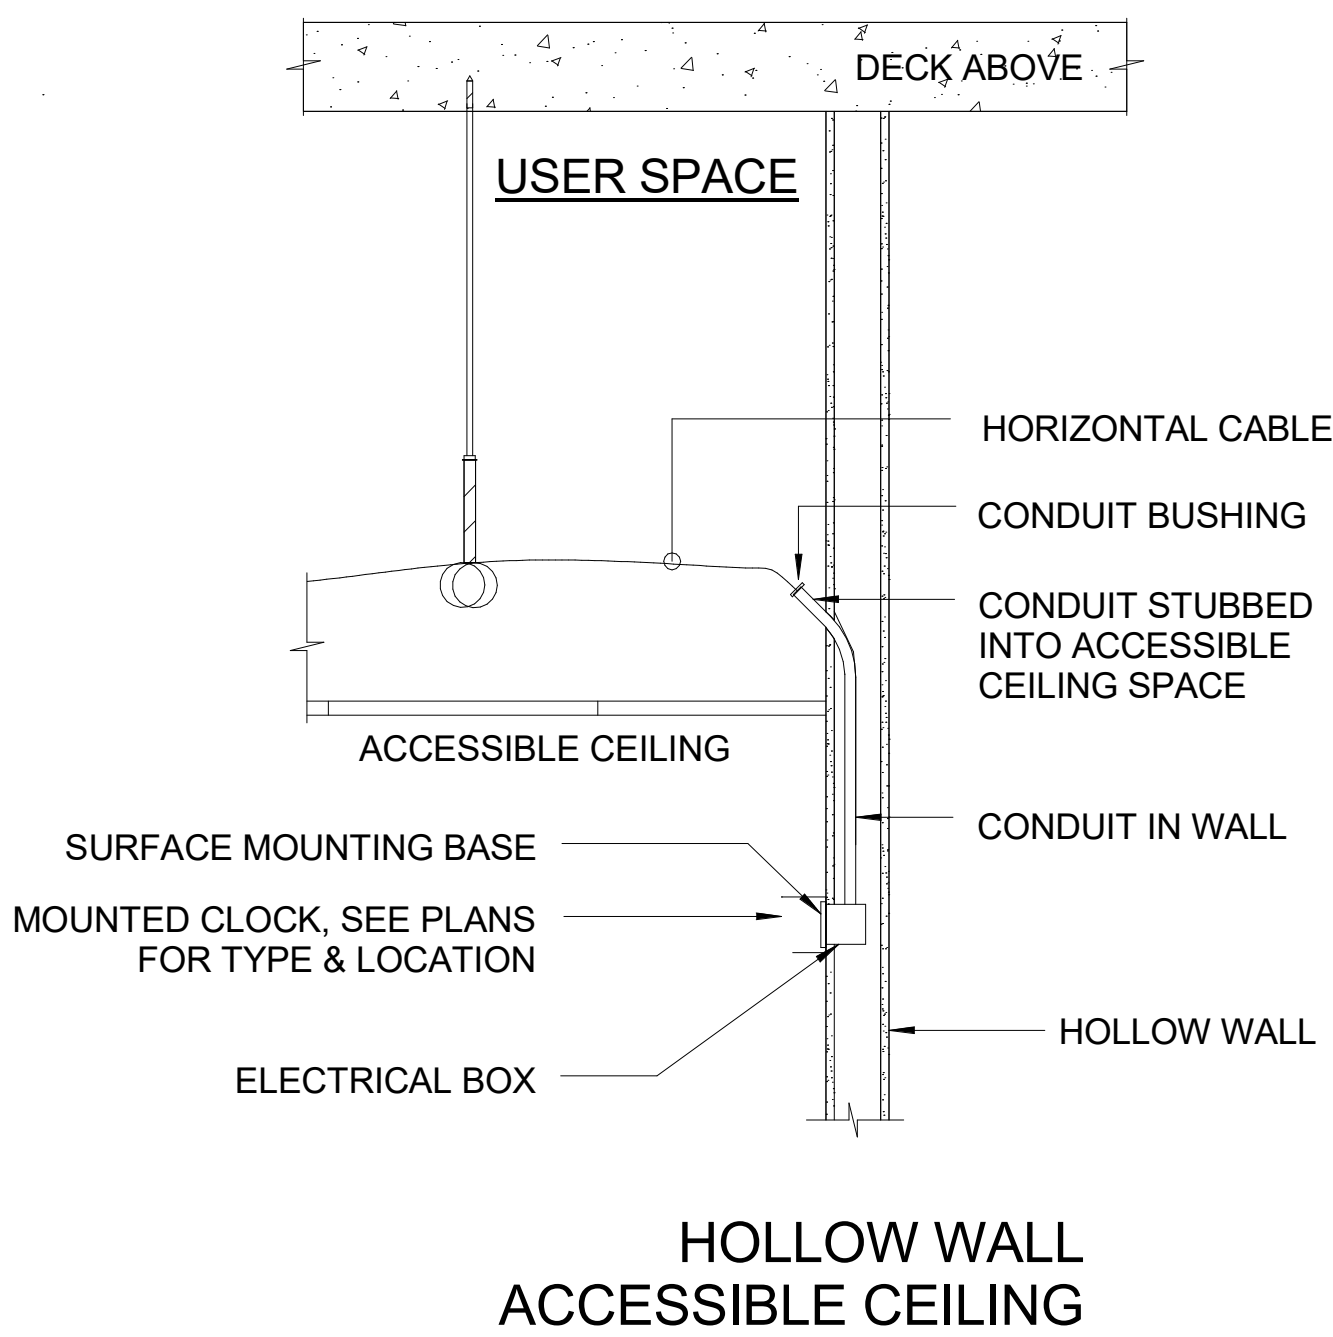

SAN ANGELO ISD
PAGING UPGRADE
SAN ANGELO, TEXAS
D-SAN-1003-01

Project:



CRUX
TECHNOLOGY • SECURITY SOLUTIONS
800.665.6440
www.cruxsolutions.com

TELECOM - DETAILS

Job No.
D-SAN-1003-01
Drawn By:
JH
Designed By:
JH
Date:
04/29/2026

Sheet No.
T501