



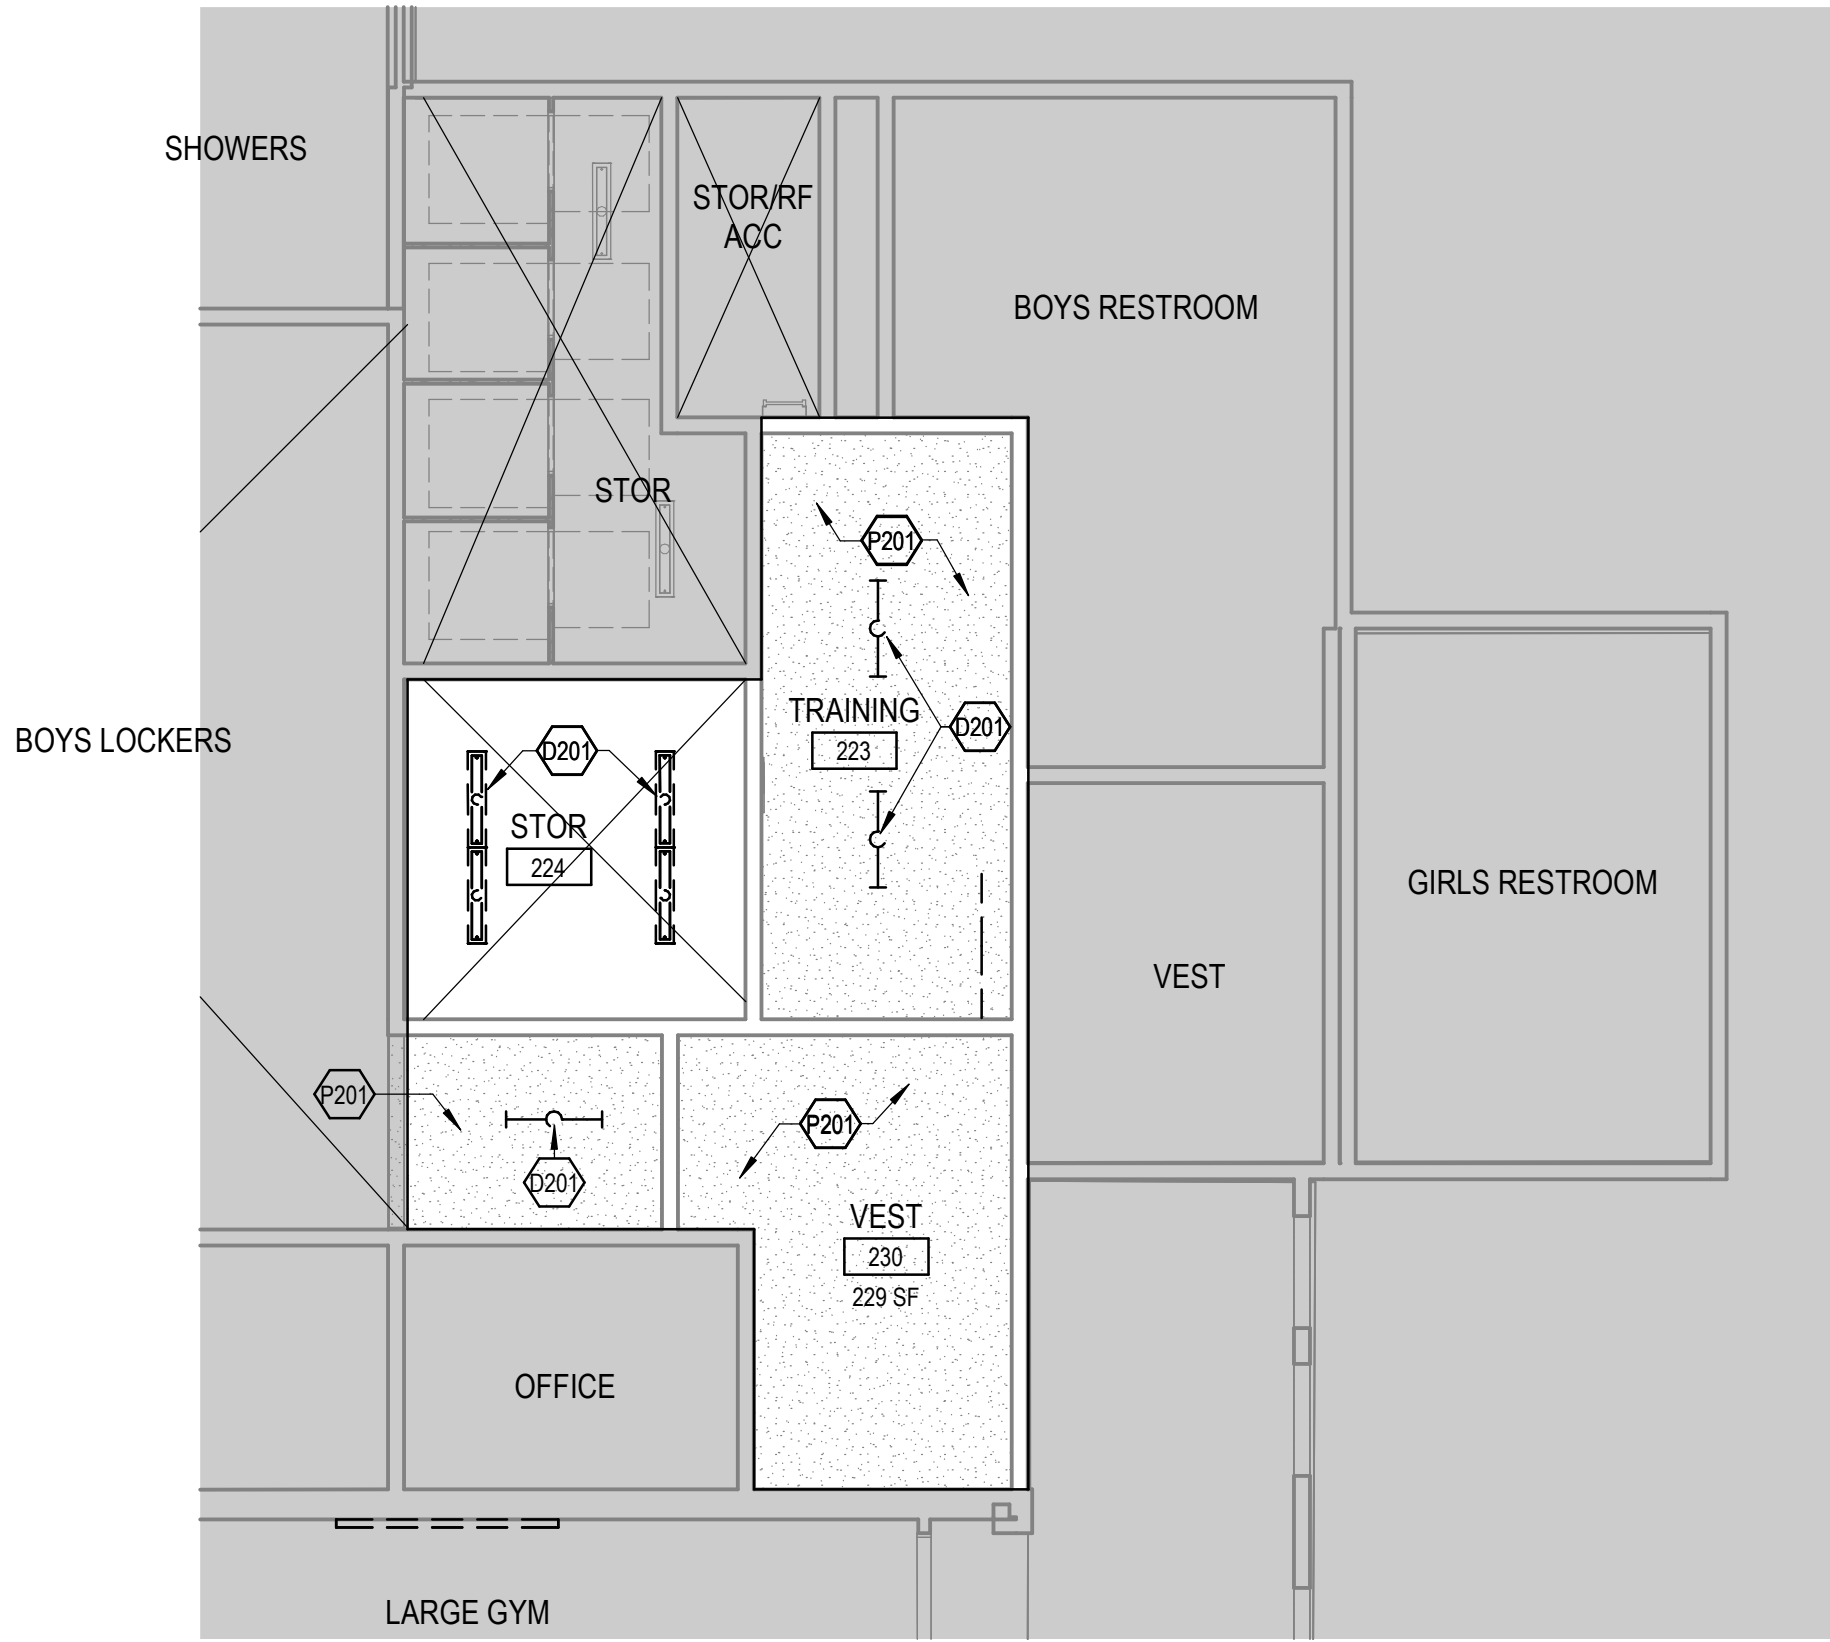

1 DEMOLITION CEILING PLAN - LEVEL 1 - OVERALL
SCALE: 1/8" = 1'-0"

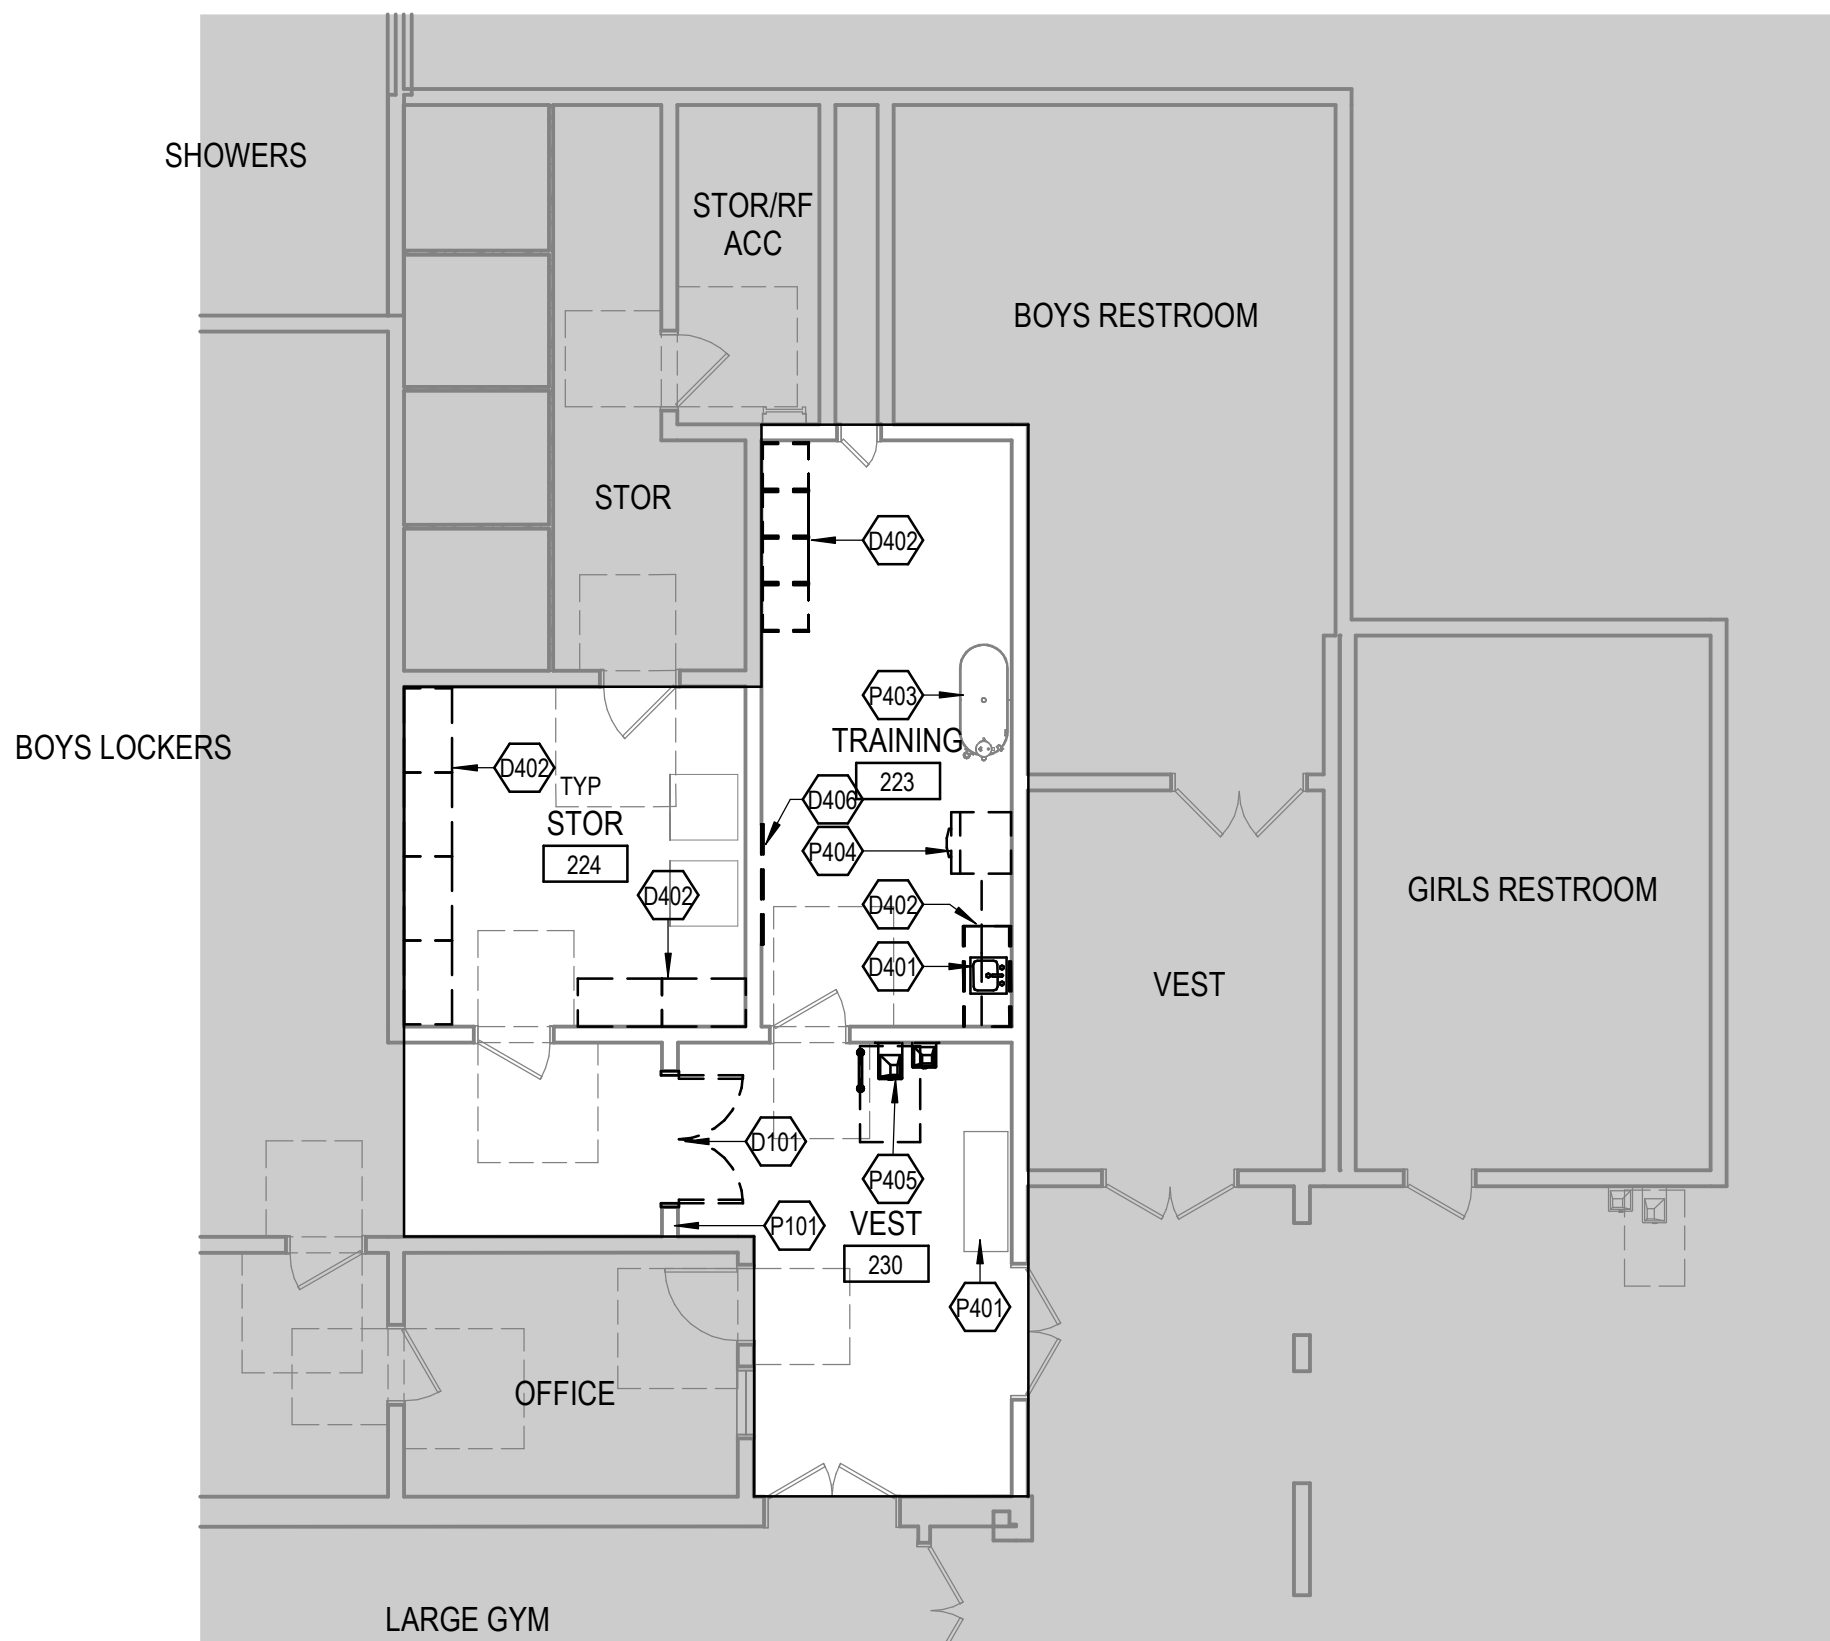

2 DEMOLITION FLOOR PLAN - LEVEL 1 - OVERALL
SCALE: 1/8" = 1'-0"



SHEET KEYNOTES

- D101 REMOVE (E) DOOR PANEL. FRAME TO REMAIN
D201 REMOVE (E) LIGHT FIXTURE
D401 REMOVE (E) PLUMBING FIXTURES, SEE PLUMBING DRAWINGS
D402 REMOVE (E) CASEWORK IN ITS ENTIRETY
D406 REMOVE (E) TACKBOARD, PREP SURFACE FOR NEW TACKBOARD
P101 (E) WALL TO REMAIN
P201 (E) GYP BOARD CEILING TO REMAIN
P401 (E) CASEWORK TO REMAIN
P403 (E) WHIRLPOOL TUB TO REMAIN
P404 (E) ICE MAKER TO BE RELOCATED, SEE FLOOR PLAN
P405 (E) DRINKING FOUNTAIN AND GRAB BARS TO BE RELOCATED, SEE FLOOR PLAN


ISSUED

MARK	DATE	DESCRIPTION
------	------	-------------

MANAGEMENT

LIONAKIS PROJECT NO.	026030
COPYRIGHT:	LIONAKIS 2017

KEY PLAN

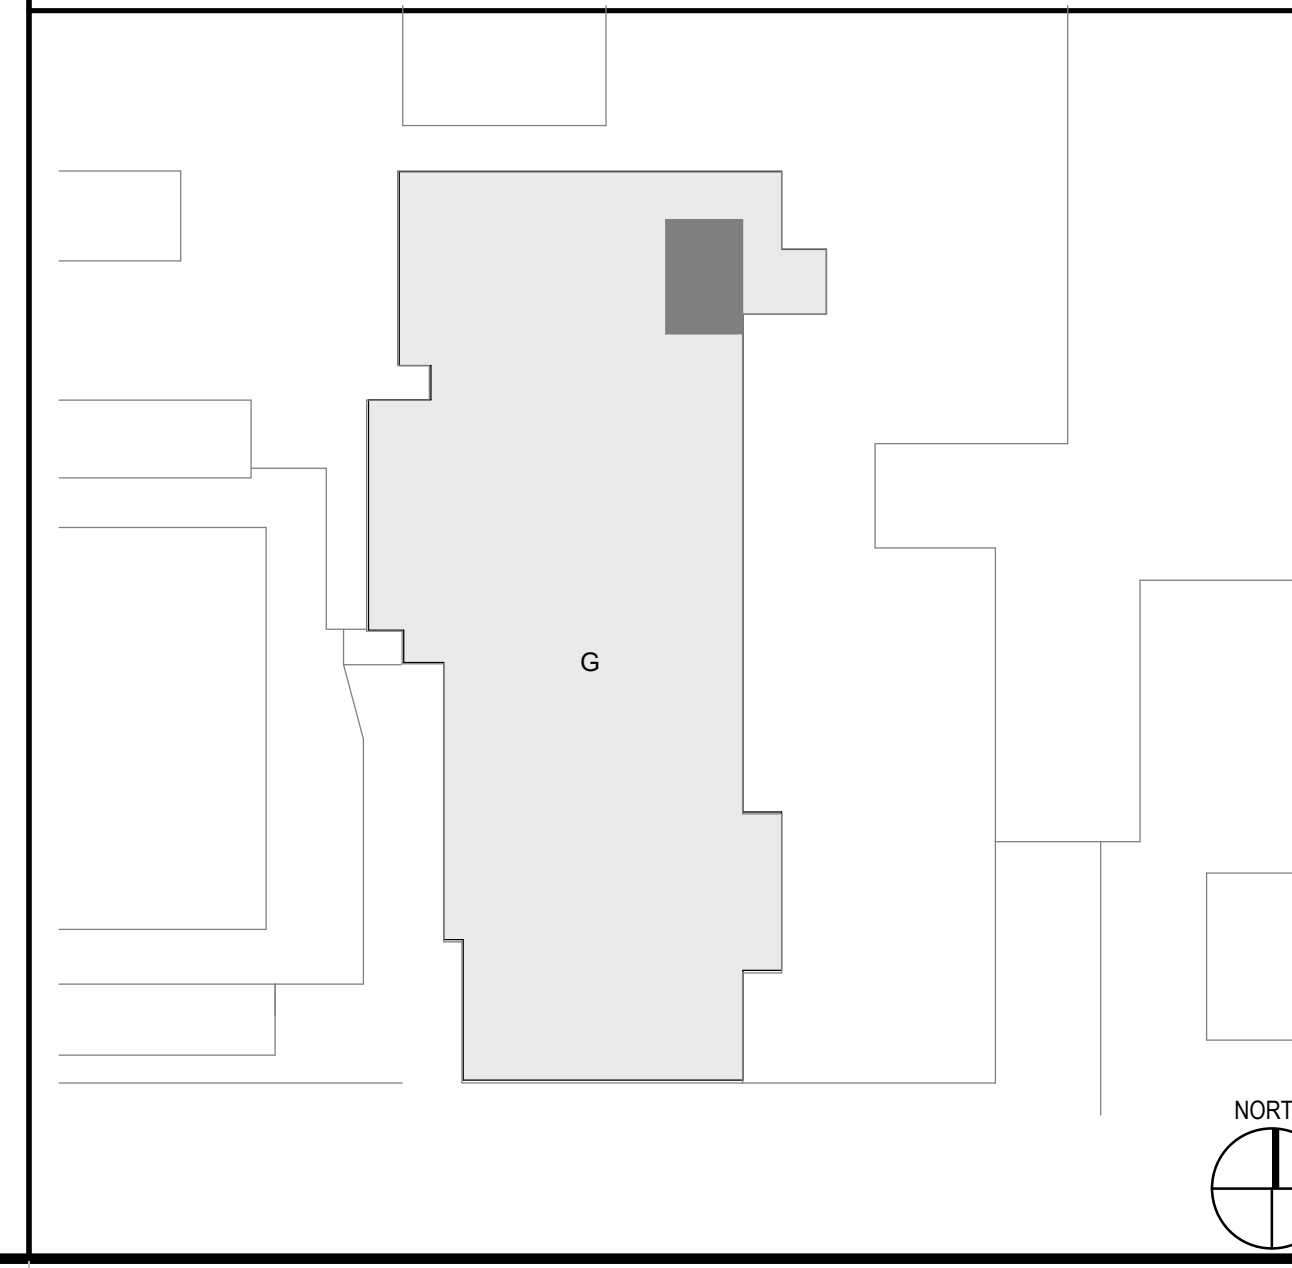

TITLE

DEMOLITION FLOOR AND CEILING PLAN - LEVEL 1


SHEET

AD111

0 1/4" 1/2" 1' 1" 2" 3" 4" 5" 6" 7" 8" 9" 10' 11' 12'


IF THIS SHEET IS NOT 30"x42", IT IS A REDUCED PRINT. SCALE ACCORDINGLY.

5/20/2024 4:22:23 PM Autodesk Docs:026030.SOUSD HS Training Rooms/026030_ARCH/METR_P&L_CENTRAL.rvt

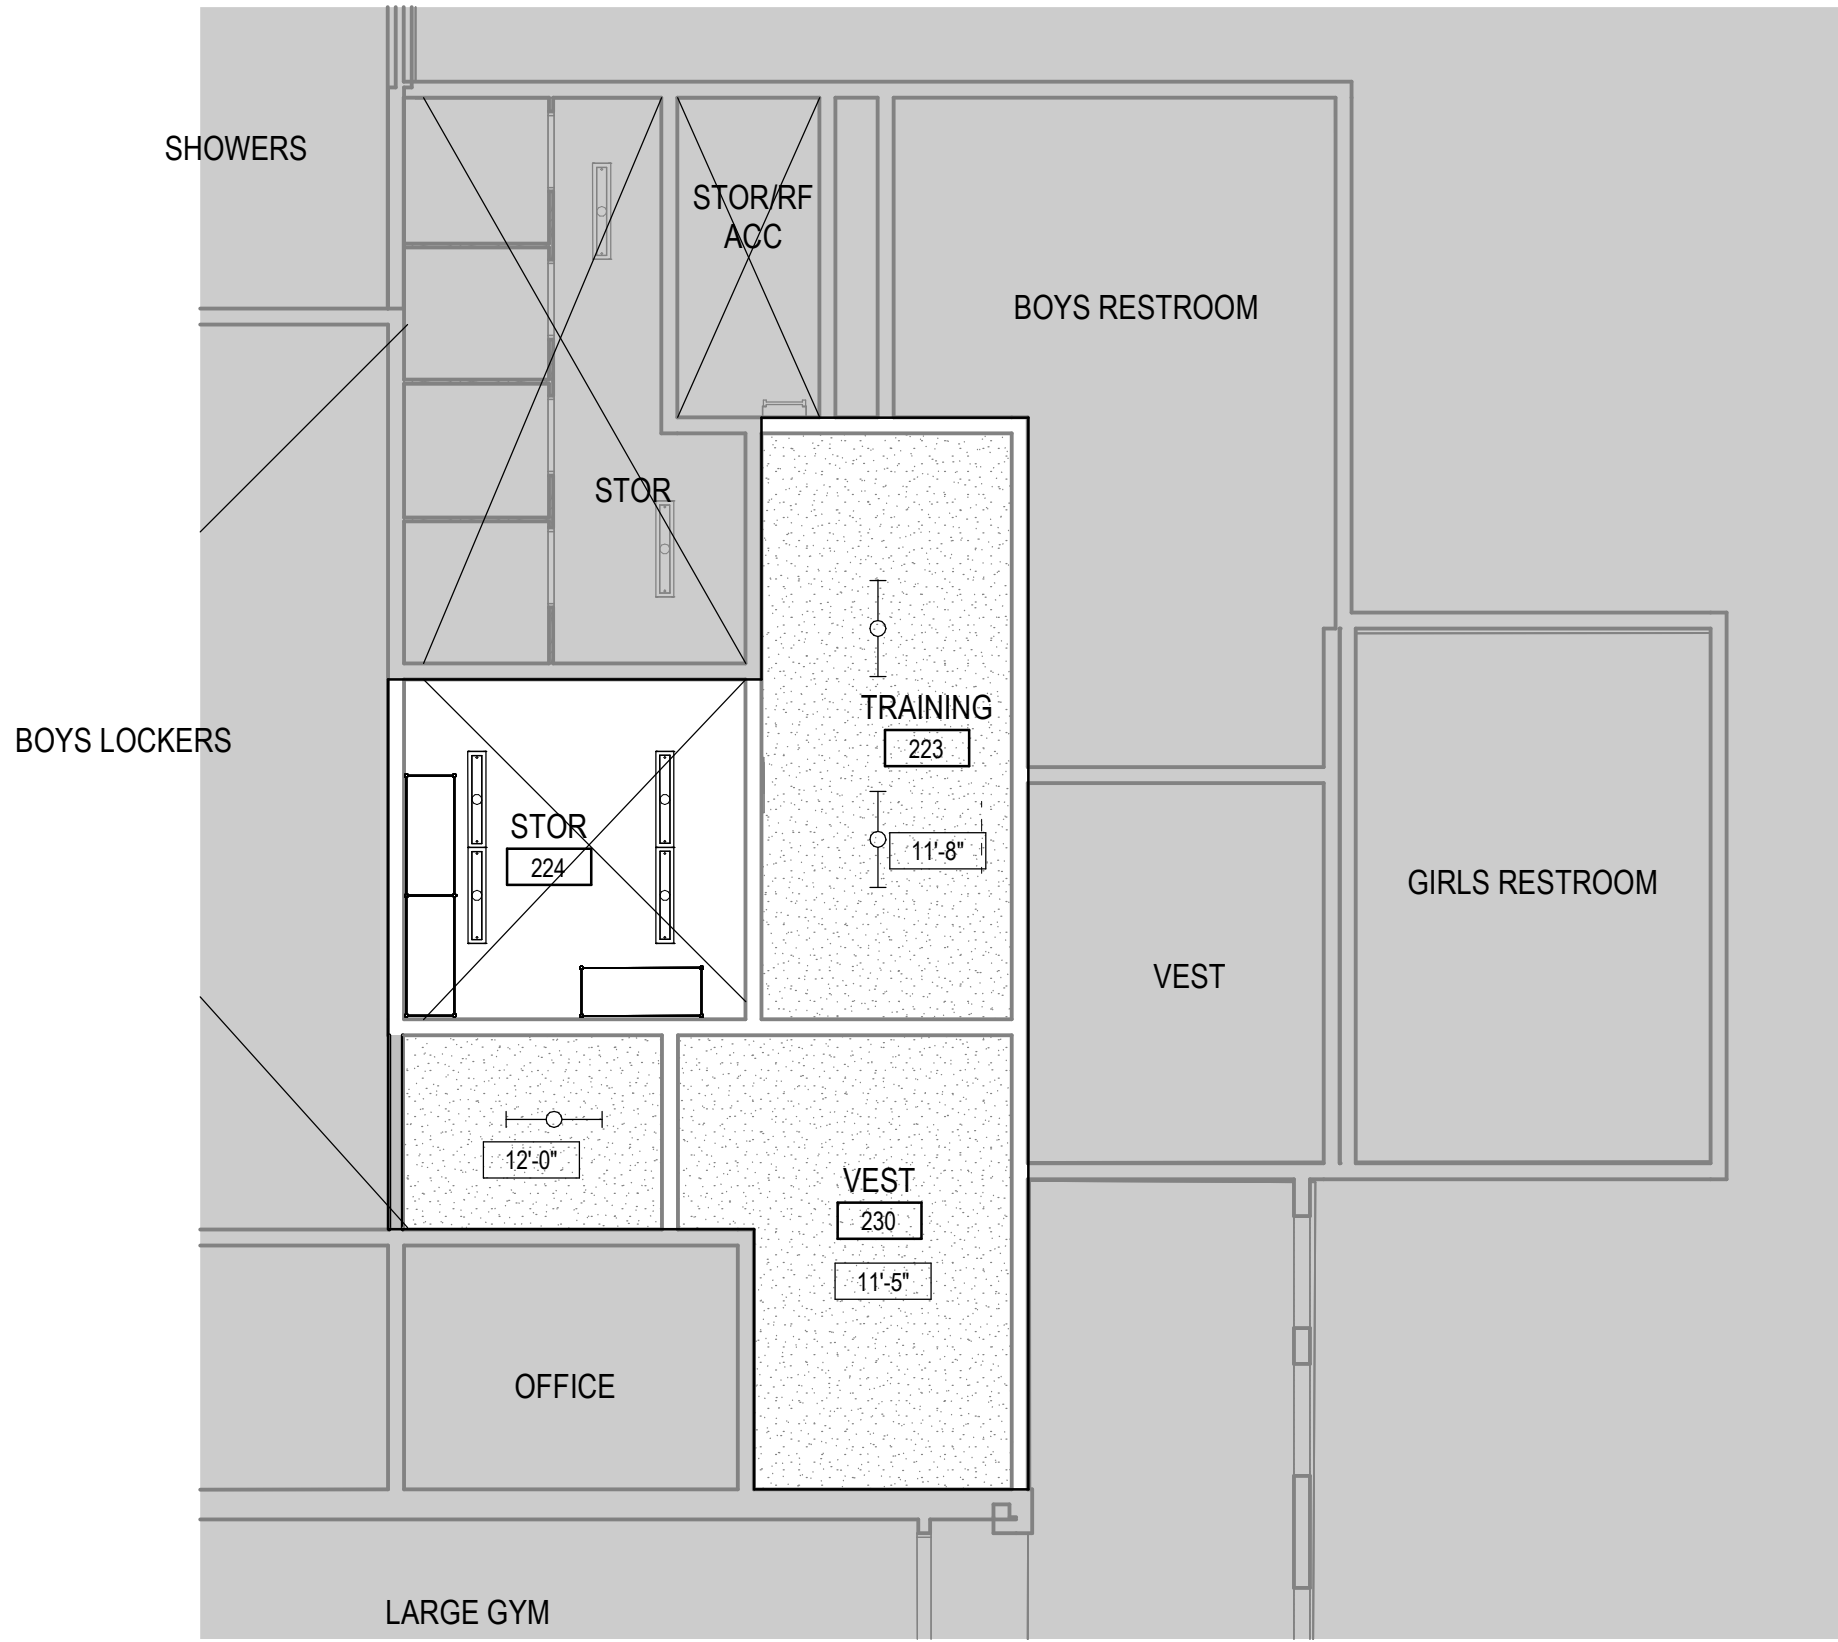

1 CEILING PLAN - LEVEL 1 - OVERALL

SCALE: 1/8" = 1'-0"

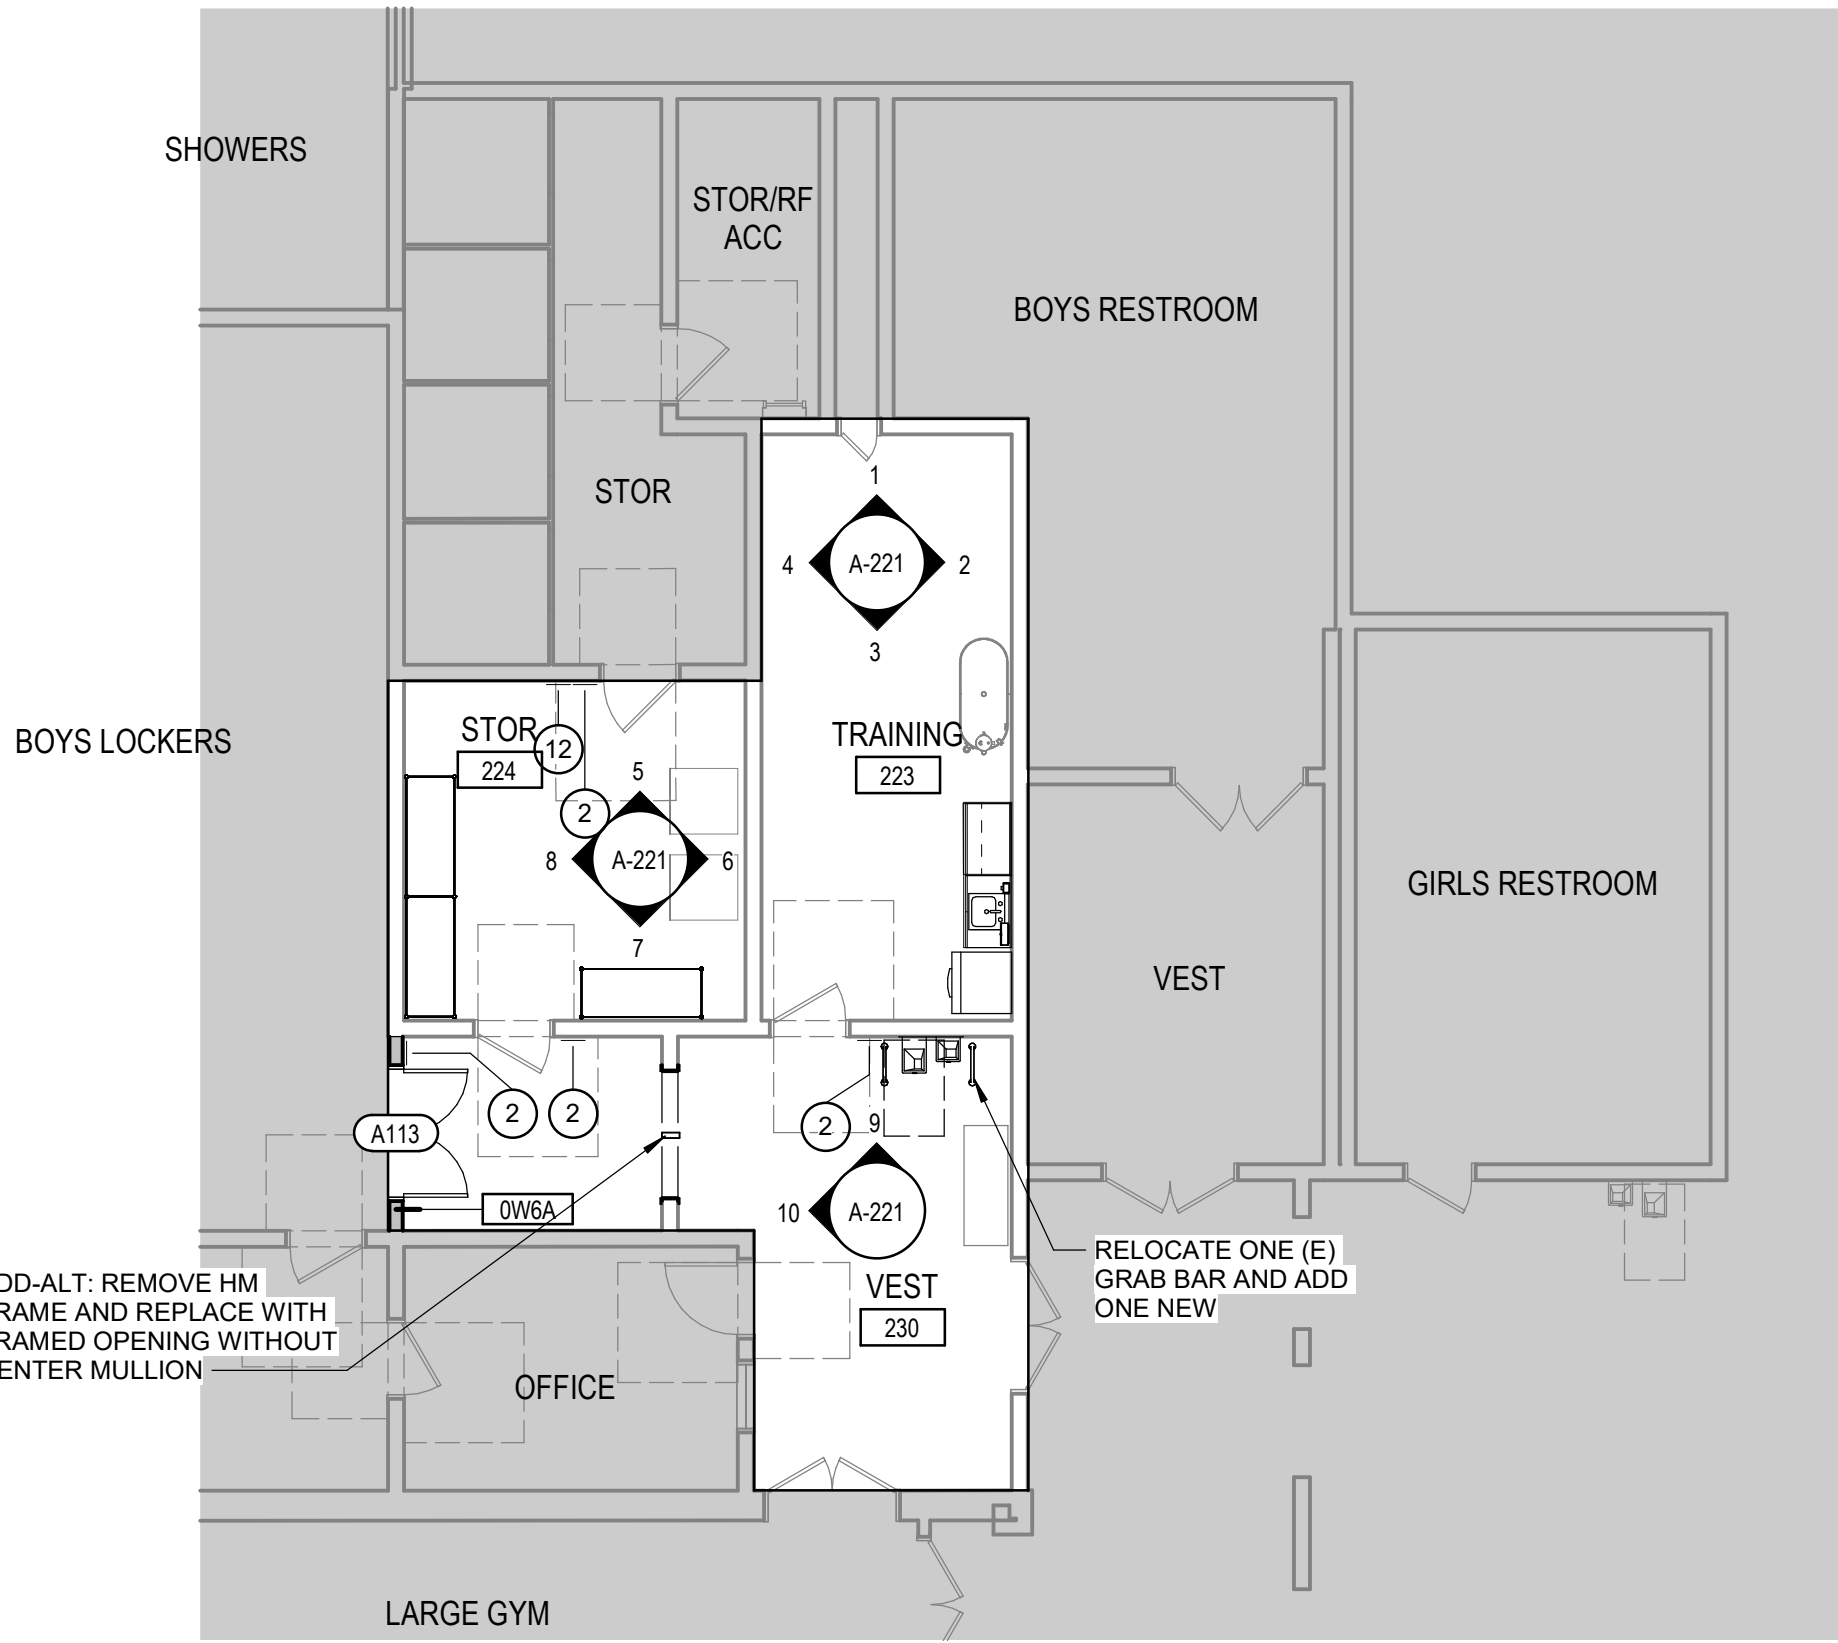

2 FLOOR PLAN - LEVEL 1 - OVERALL

SCALE: 1/8" = 1'-0"

FLOOR PLAN LEGEND

	DOOR, FOR DOOR TYPES SEE 2A-621
	DOOR NUMBER, SEE DOOR SCHEDULE ON SHEET 2A-621
	(E) DOOR TO REMAIN
	WALL TYPE, SEE SHEET 2A-531
	ROOM NAME AND NUMBER
	FURNITURE, FIXTURE & EQUIPMENT INDICATOR
	UNRATED WOOD STUD WALL, SEE 2A-531

SIGNAGE LEGEND


1	FUNCTIONAL ROOM SIGNAGE, SEE DETAIL	19 / A-521
12	ELECTRICAL PANEL SIGNAGE LOCATION	17 / A-521

CEILING PLAN LEGEND

	CEILING HEIGHT ELEVATION
	PAINTED GYPSUM BOARD CEILING
	EXPOSED - OPEN TO ABOVE OR TO CEILING HEIGHT ELEVATION
	LIGHT FIXTURES, SEE ELECTRICAL DRAWINGS

SHEET KEYNOTES

KEY PLAN

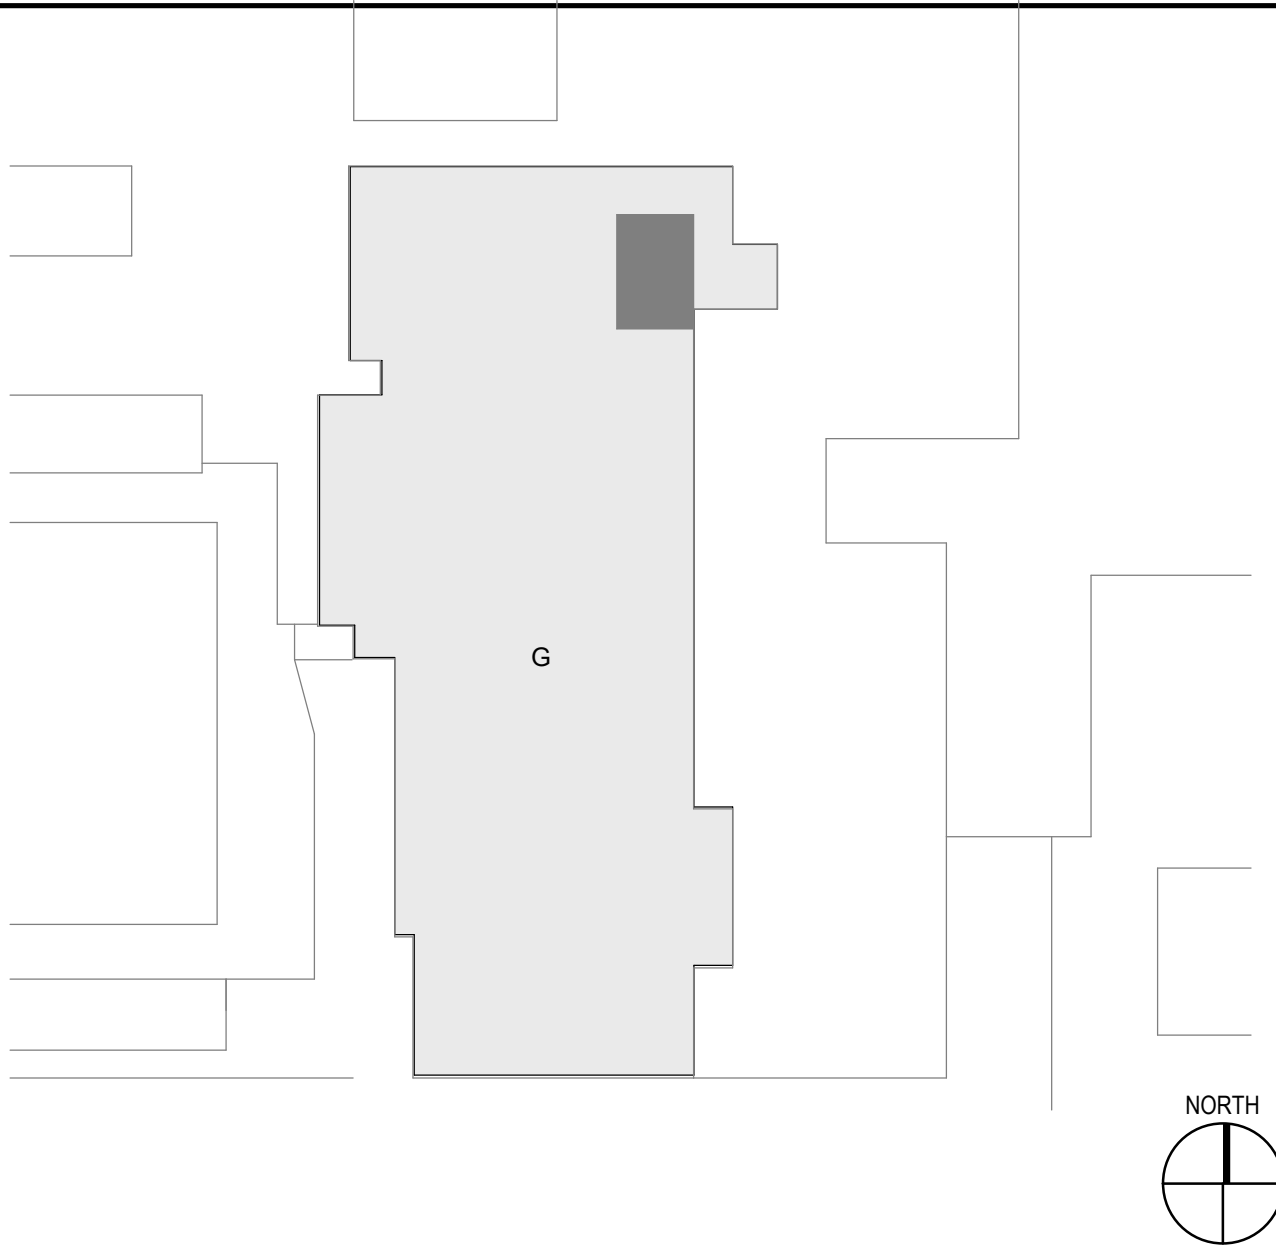

LIONAKIS

2025 Nineteenth Street
Sacramento CA 95818
P 916.558.1900
www.lionakis.com

CONSULTANT

SEAL



PROJECT
MCCLATCHY HS TRAINING ROOM

3066 FREEPORT BLVD
SACRAMENTO, CA 95818

CLIENT
SACRAMENTO CITY UNIFIED SCHOOL DISTRICT
5735 47TH AVE, SACRAMENTO CA 95824

ISSUED

MARK	DATE	DESCRIPTION
------	------	-------------

MANAGEMENT


LIONAKIS PROJECT NO. 026030
COPYRIGHT: LIONAKIS 2017

TITLE


FLOOR AND CEILING
PLAN - LEVEL 1

SHEET


A-111

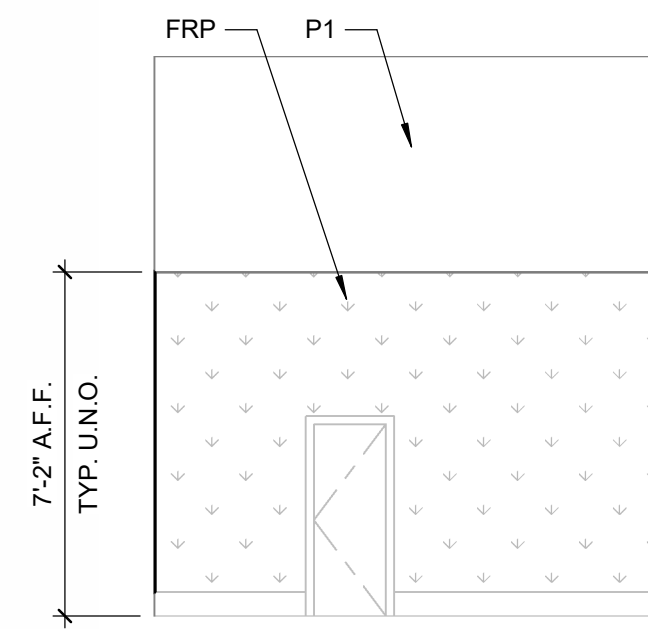


1 TRAINING - NORTH
SCALE 1/4" = 1'-0"

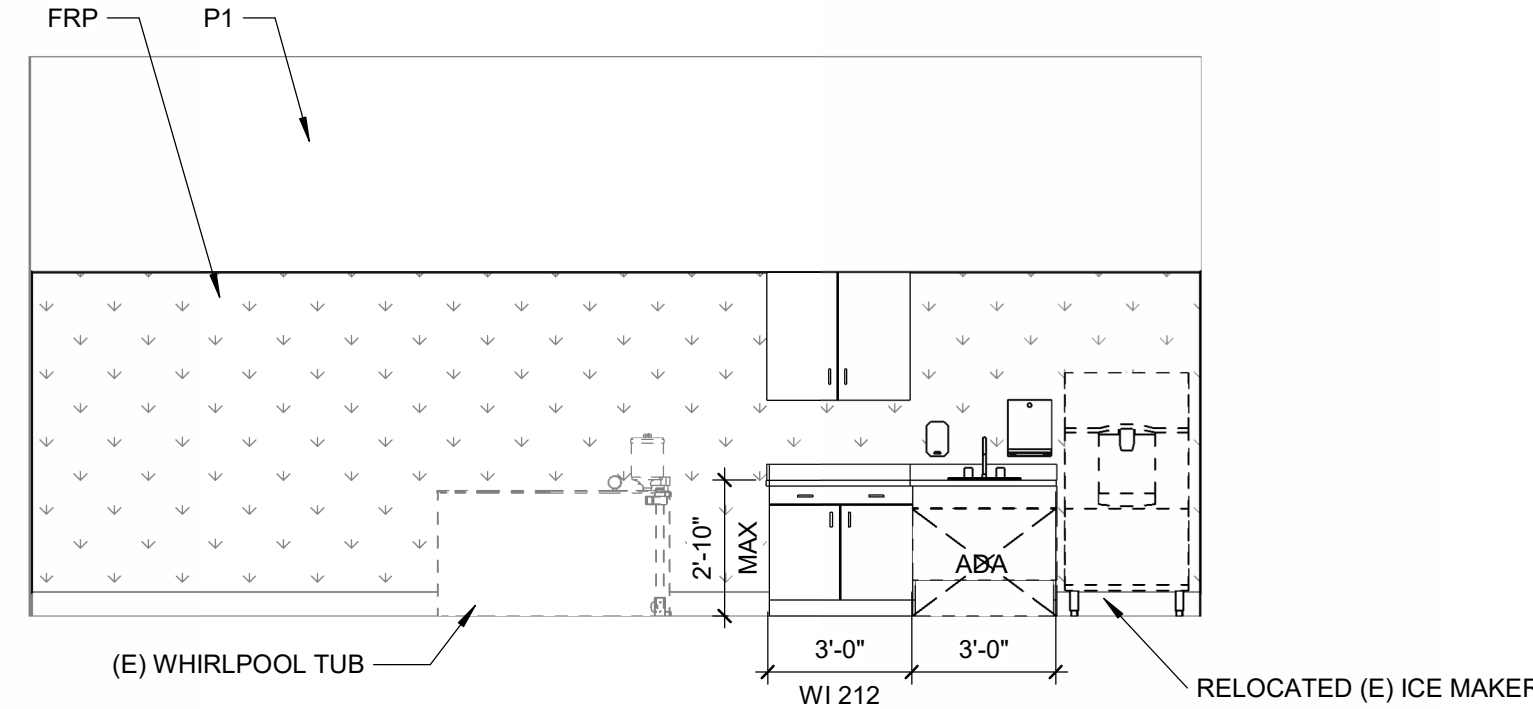


2 TRAINING - EAST
SCALE 1/4" = 1'-0"

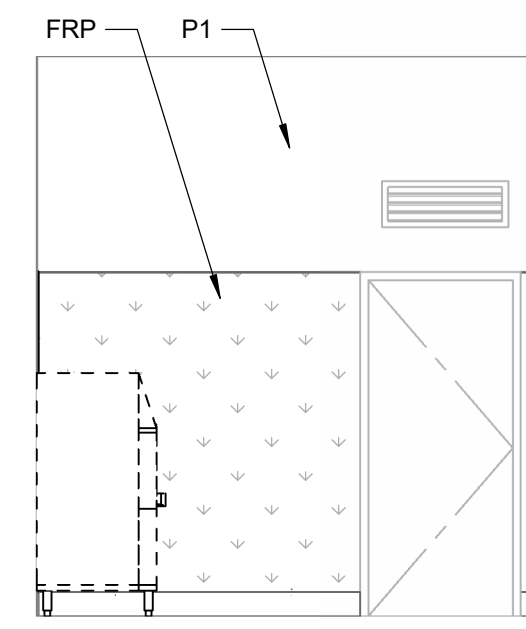


3 TRAINING - SOUTH
SCALE 1/4" = 1'-0"

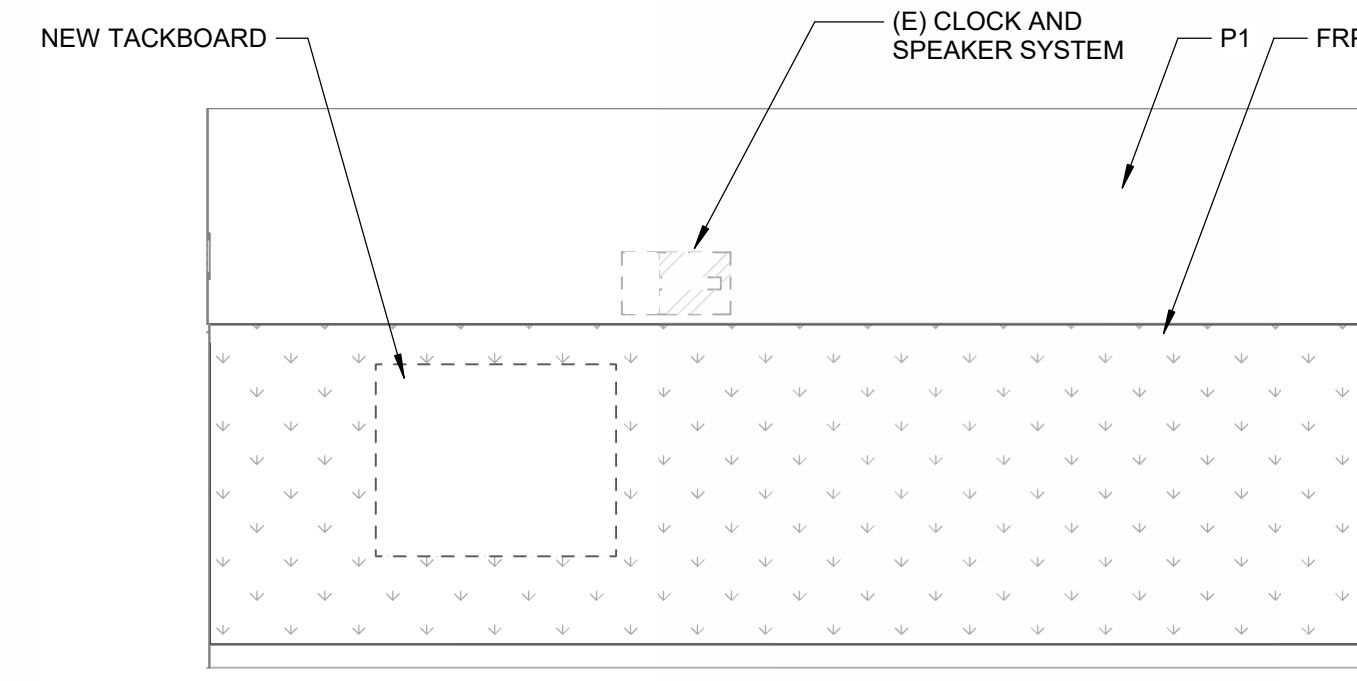


4 TRAINING - WEST
SCALE 1/4" = 1'-0"

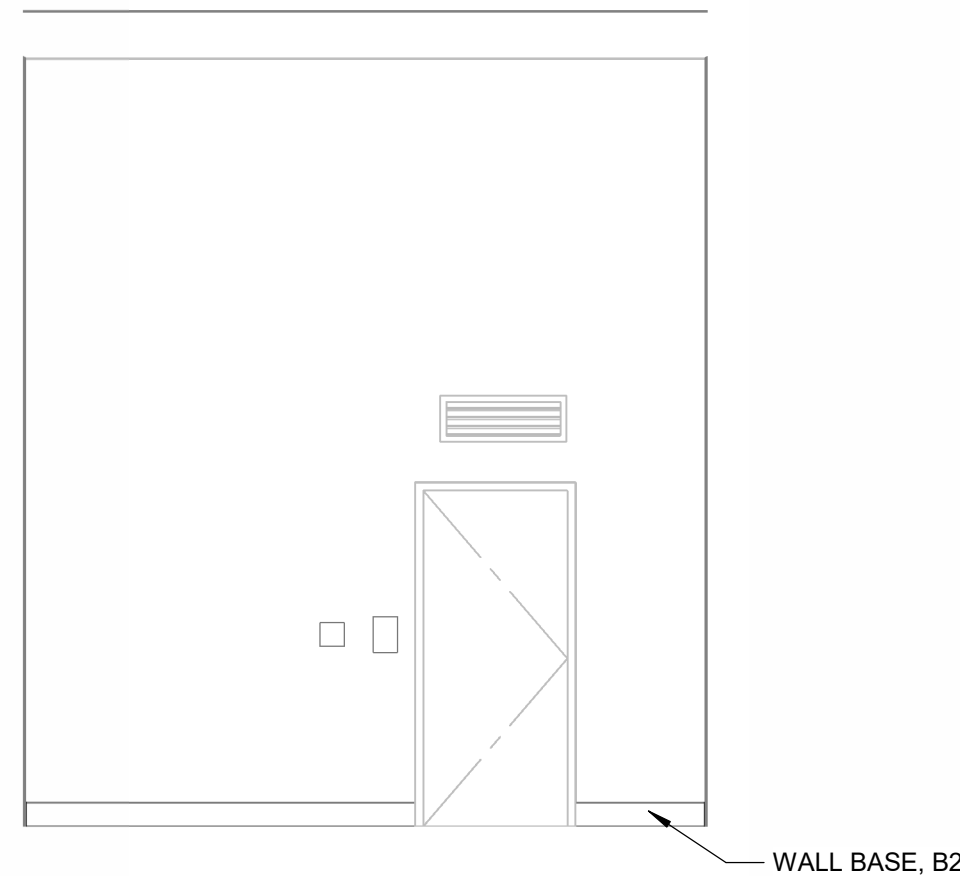


5 STORAGE - NORTH
SCALE 1/4" = 1'-0"

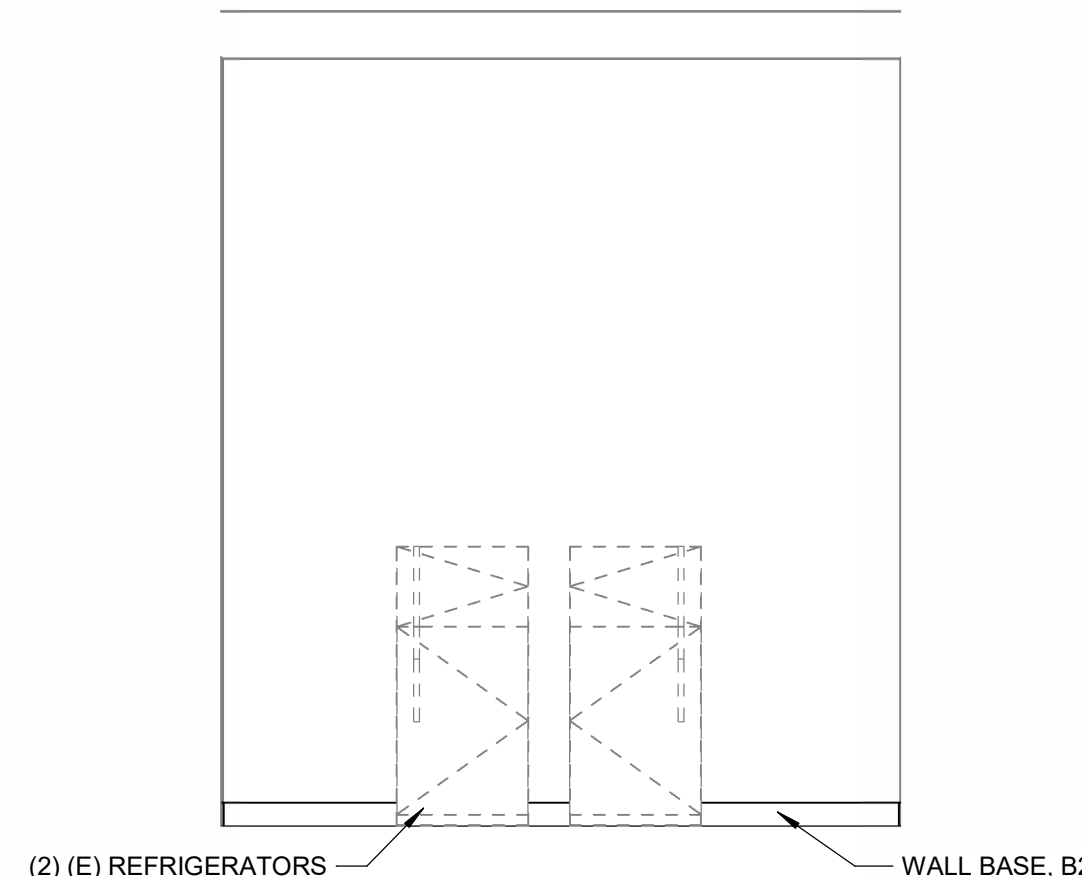


6 STORAGE - EAST
SCALE 1/4" = 1'-0"

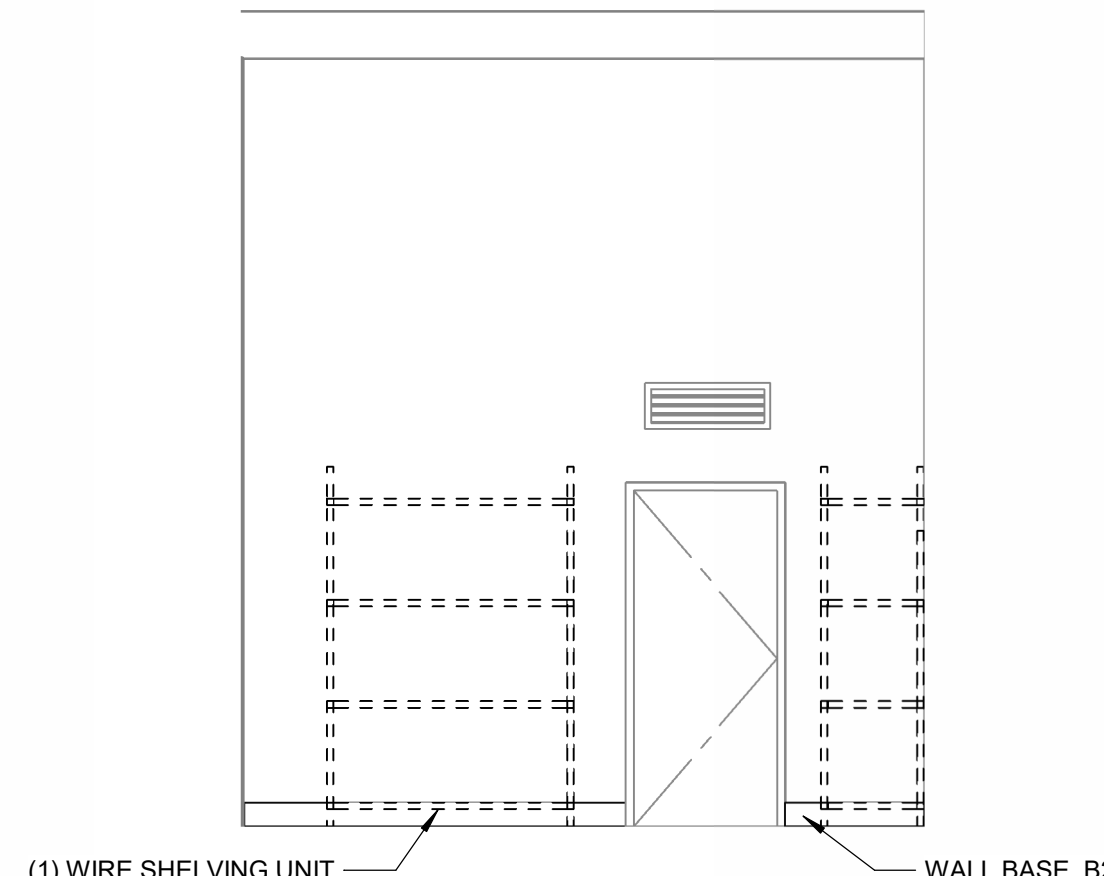


7 STORAGE - SOUTH
SCALE 1/4" = 1'-0"

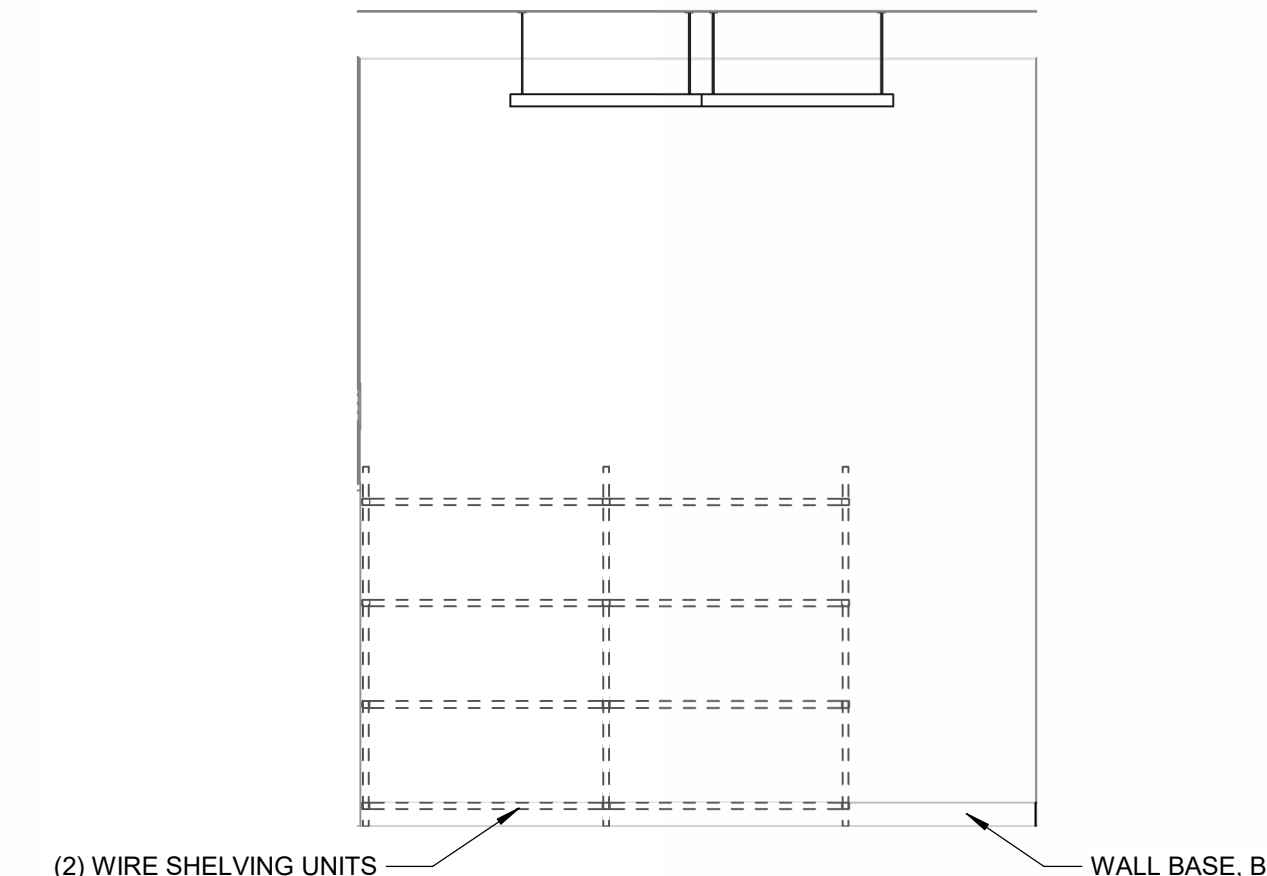

8 STORAGE - WEST
SCALE 1/4" = 1'-0"

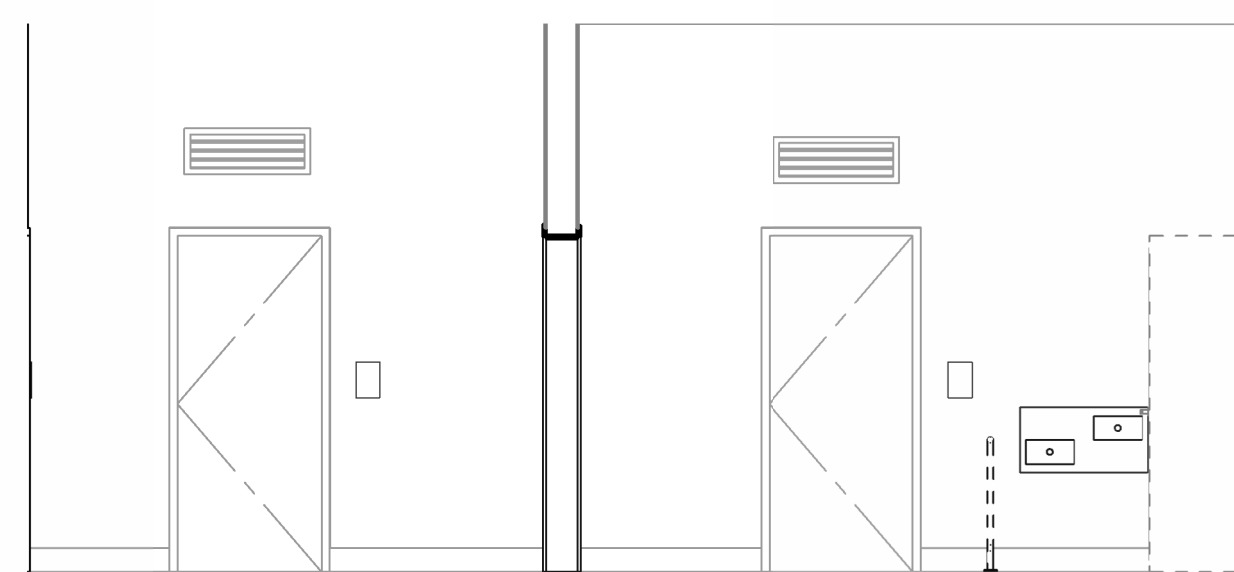


9 VESTIBULE - NORTH
SCALE 1/4" = 1'-0"

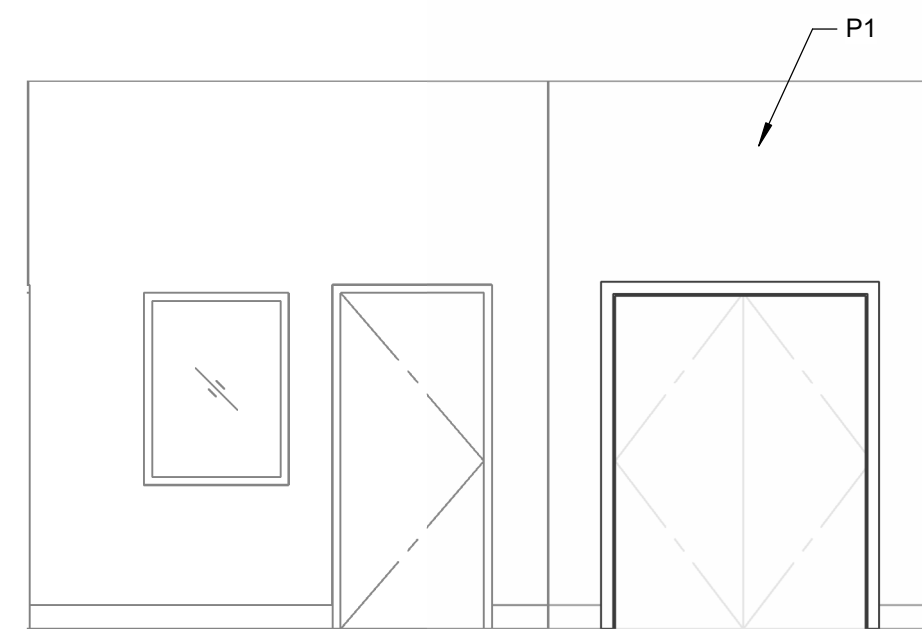

10 VESTIBULE - WEST
SCALE 1/4" = 1'-0"

KEY PLAN

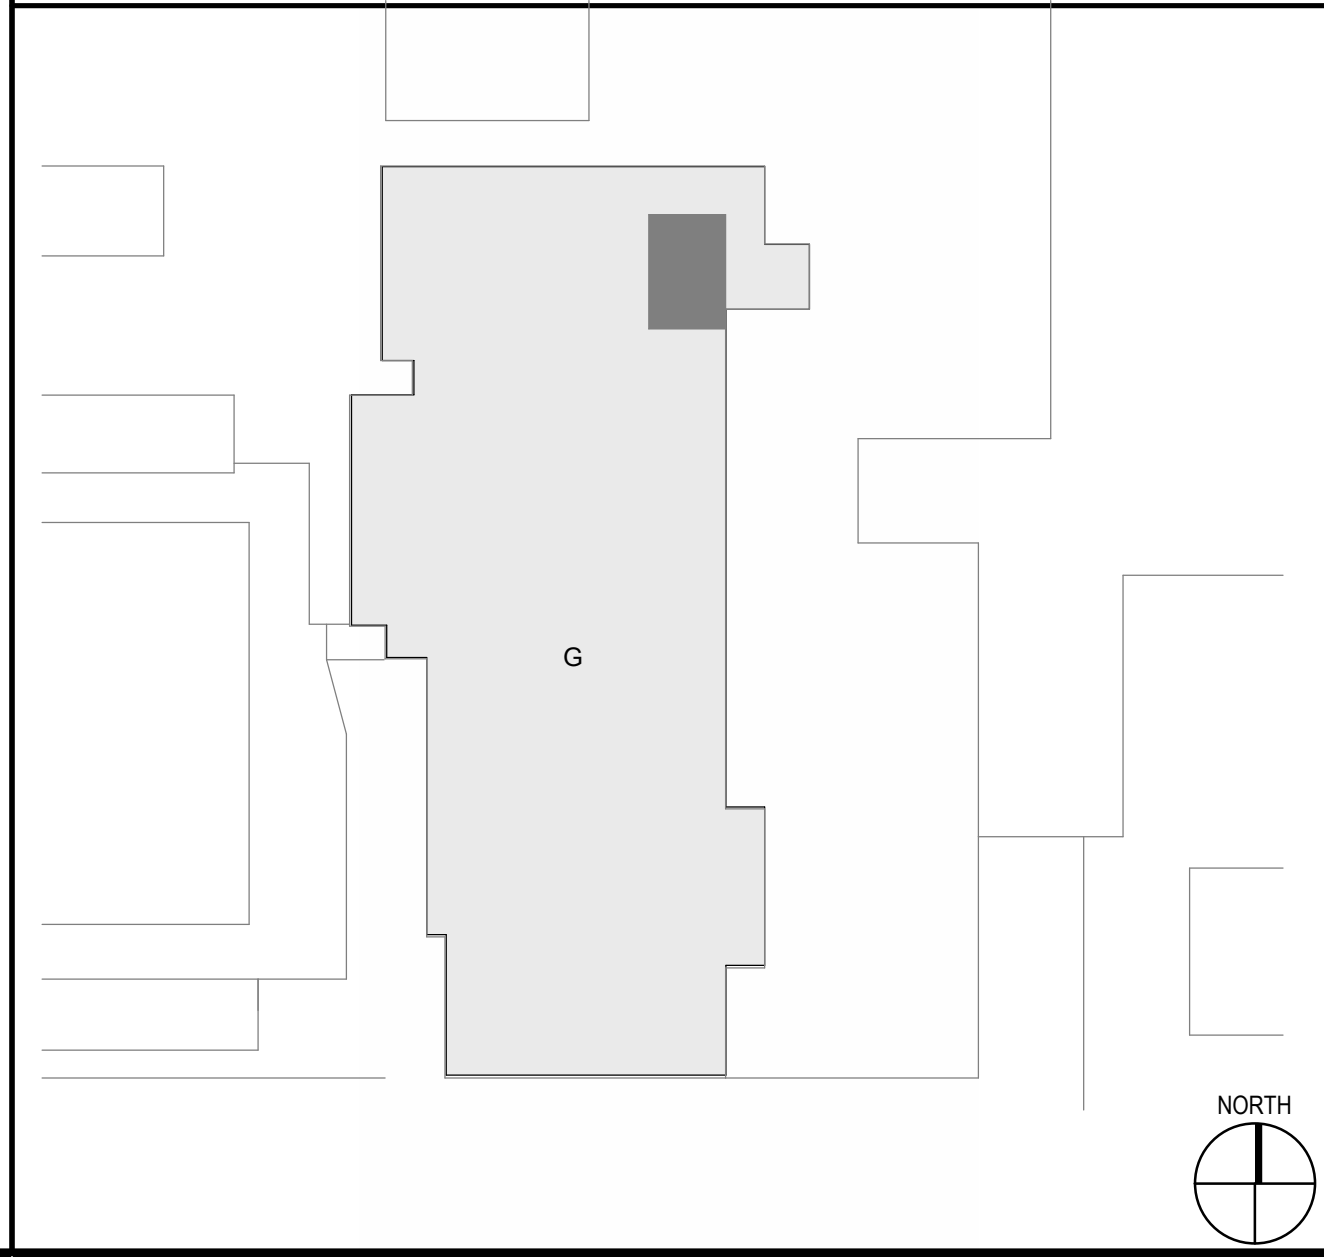

LIONAKIS

2025 Nineteenth Street
Sacramento CA 95818
P 916.558.1900
www.lionakis.com

CONSULTANT

SEAL



PROJECT
MCCLATCHY HS TRAINING ROOM

3066 FREEPORT BLVD
SACRAMENTO, CA 95818

CLIENT
SACRAMENTO CITY UNIFIED SCHOOL DISTRICT
5735 47TH AVE, SACRAMENTO CA 95824

ISSUED

MARK	DATE	DESCRIPTION
------	------	-------------

MANAGEMENT


LIONAKIS PROJECT NO.: 026030
COPYRIGHT: LIONAKIS 2017

TITLE

ELEVATIONS - INTERIOR

SHEET

A-221

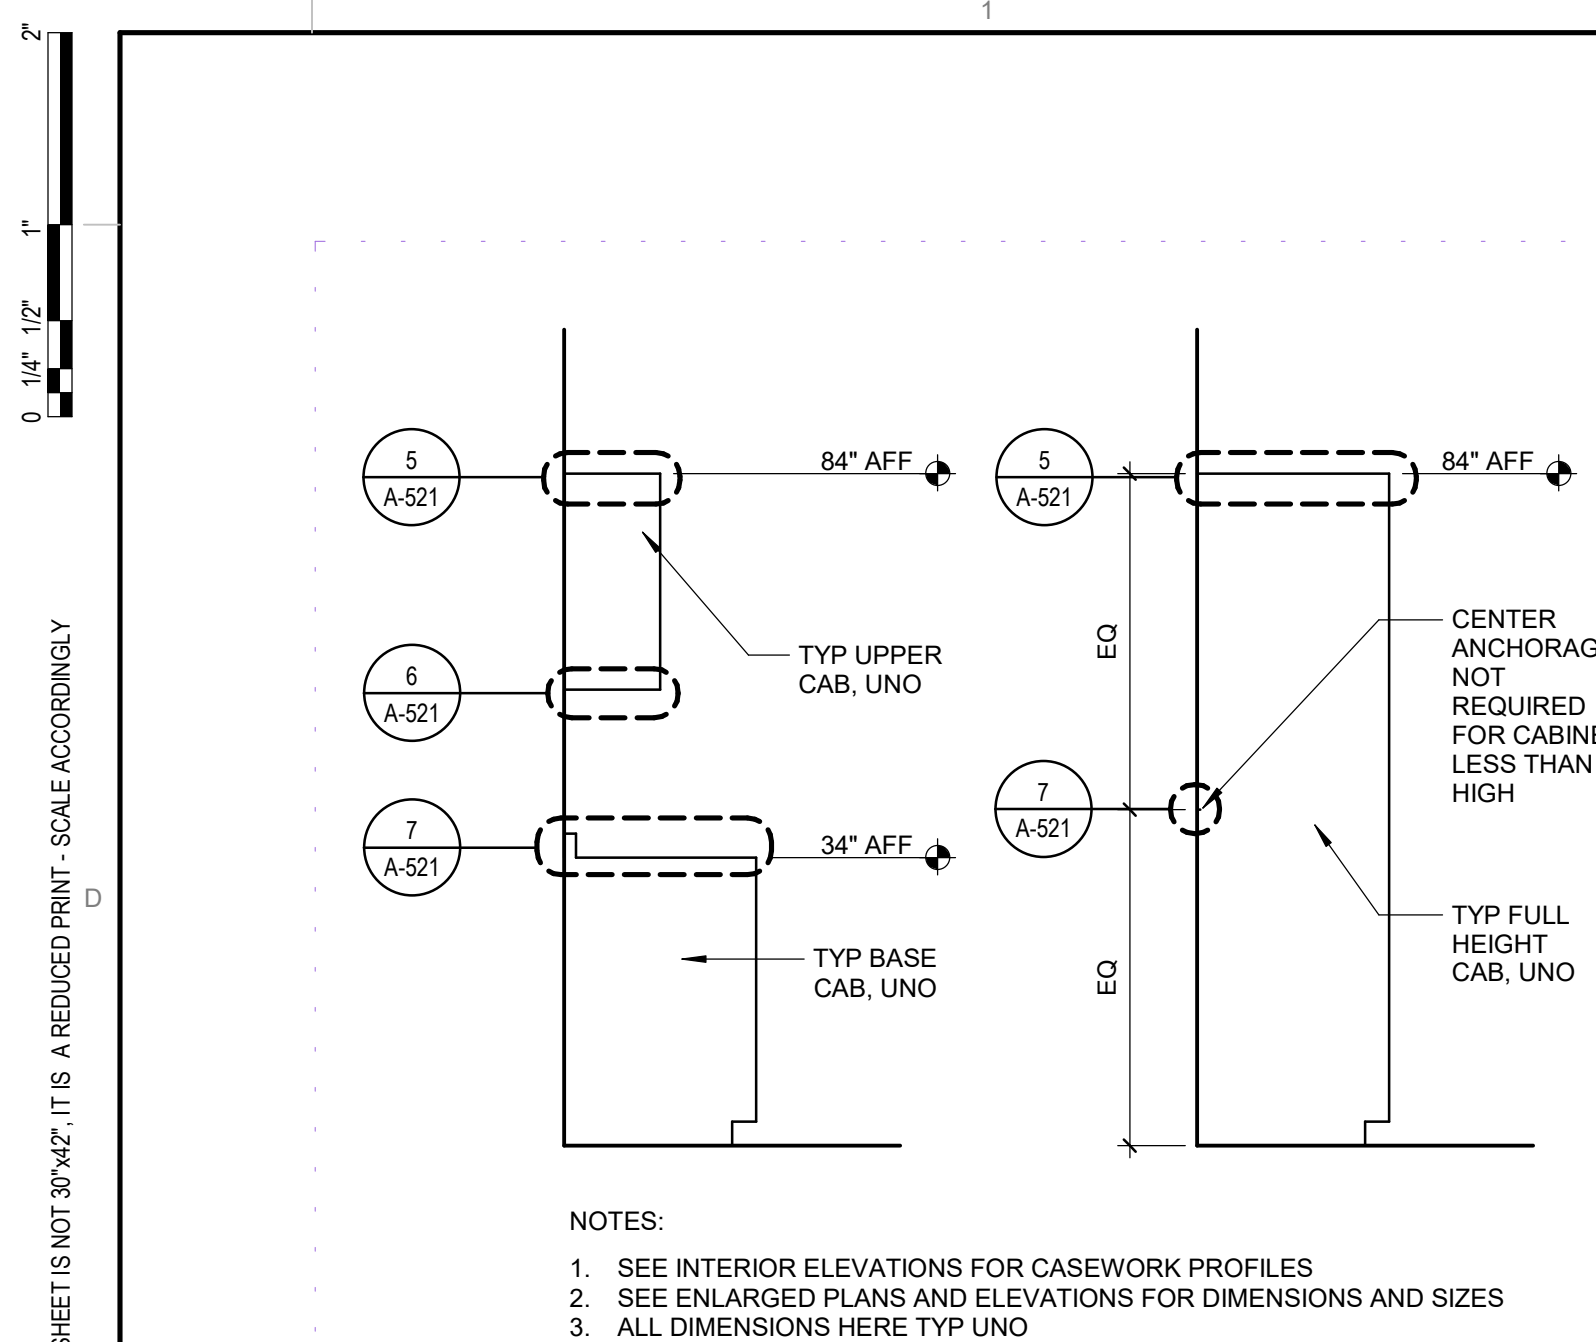


1 TYP CASEWORK ANCHORAGE

3\"/>

WOOD STUD	#14 ROUND WASHER HEAD WOOD SCREW W/ 1 1/2\"/>
CONCRETE	ATTACH TO CONC SLAB W/ 0.145\"/>


2 TYP CASEWORK FASTENERS WOOD FRAMING

3\"/>

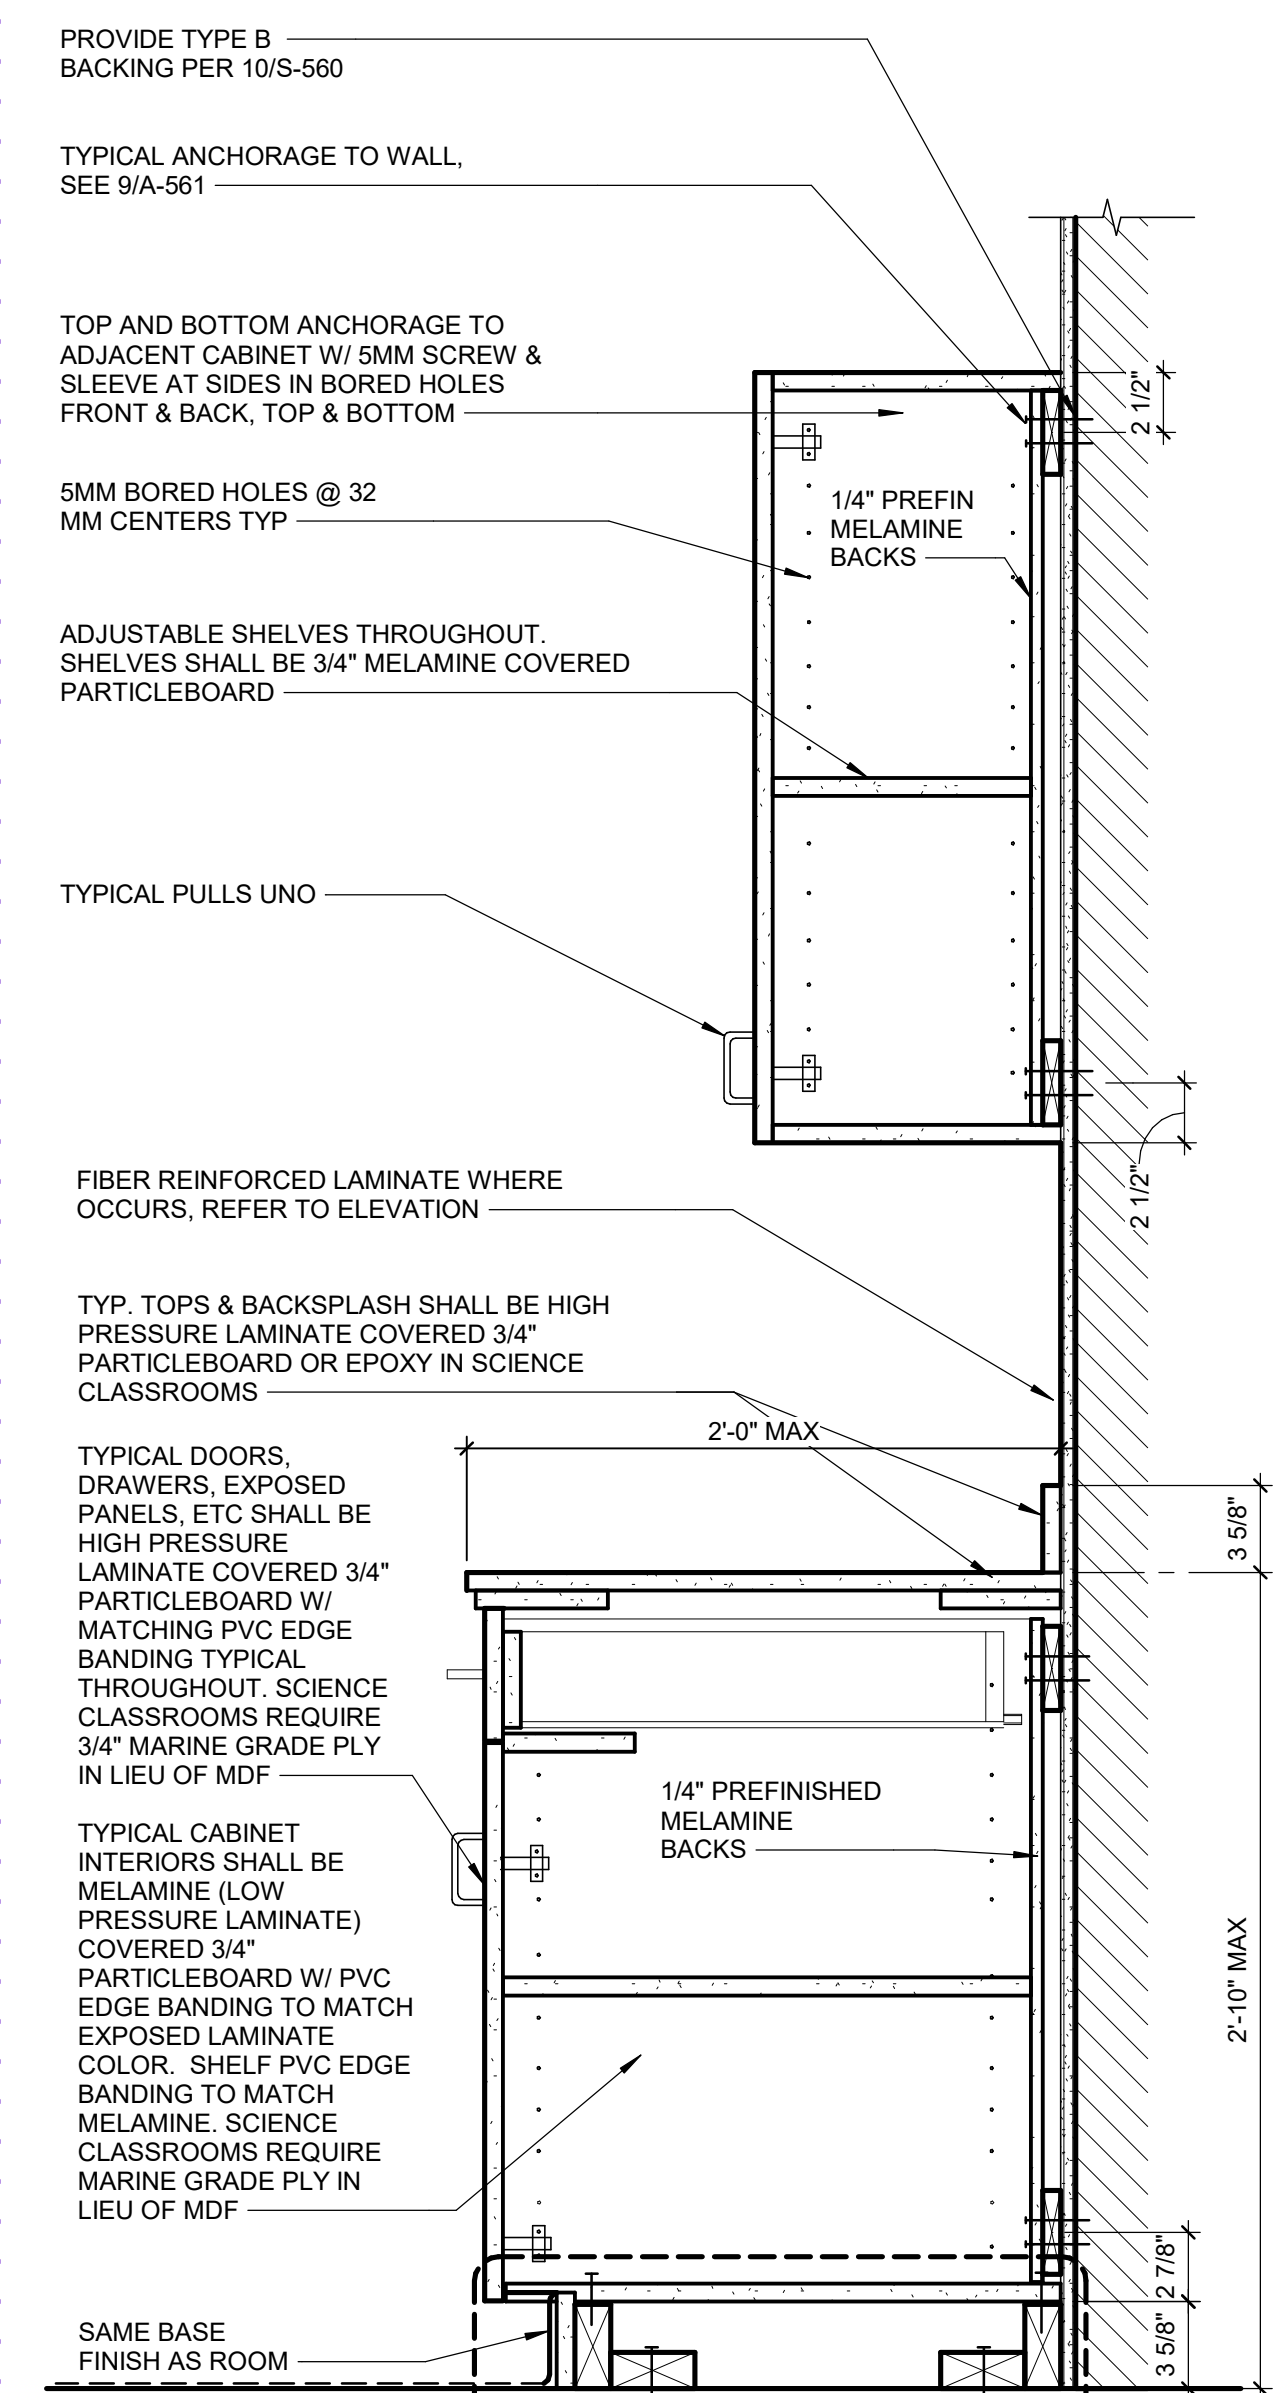


4 TYPICAL CASEWORK SECTION

1 1/2\"/>

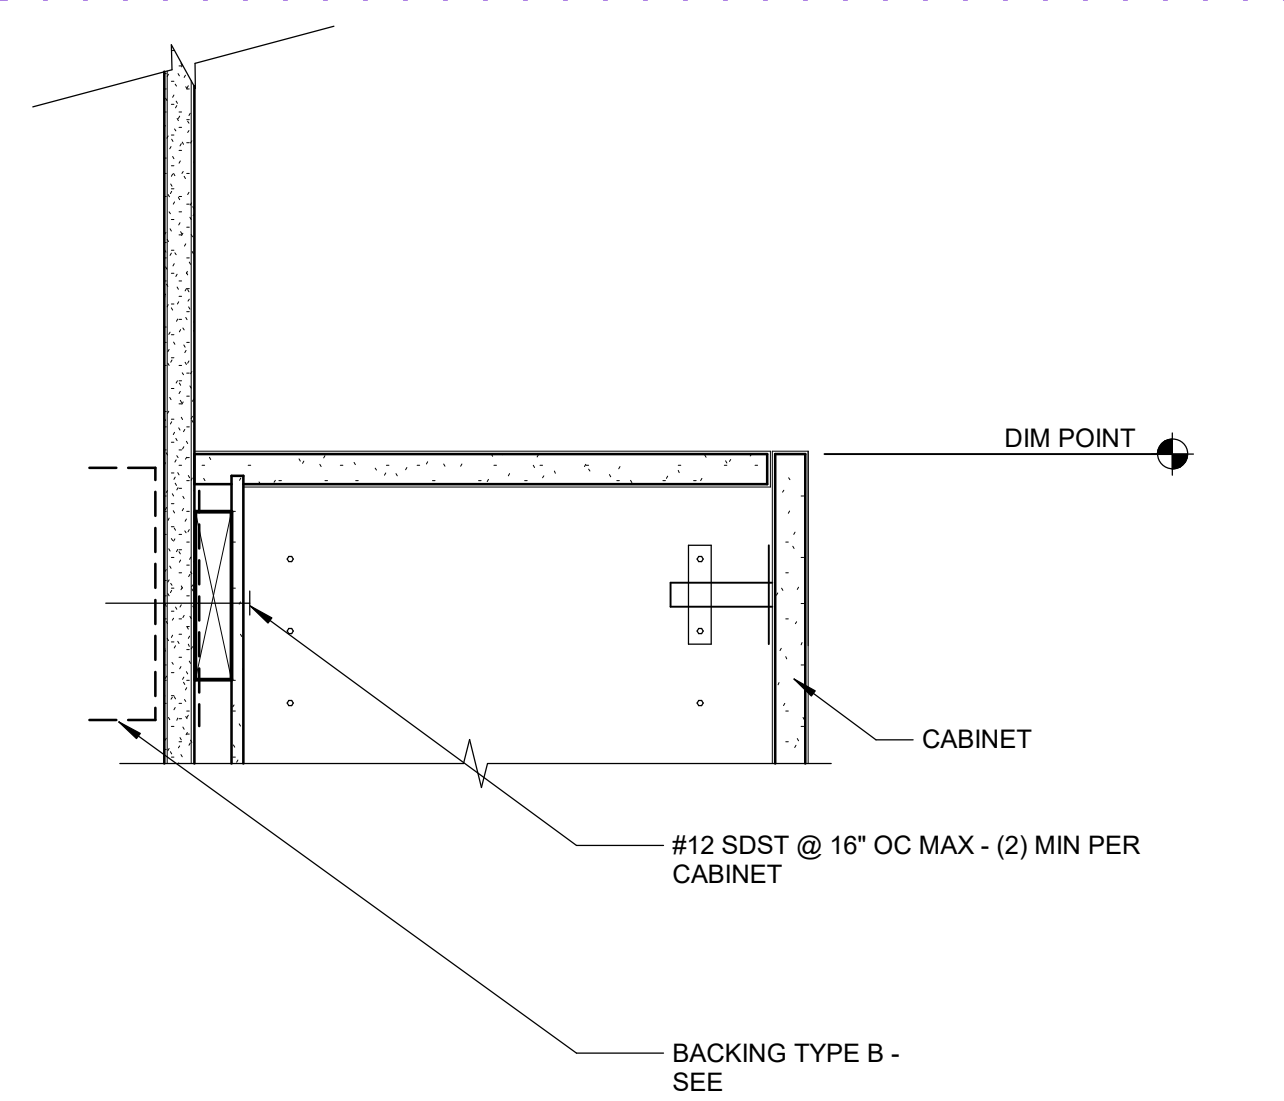


5 UPPER CASEWORK

3\"/>

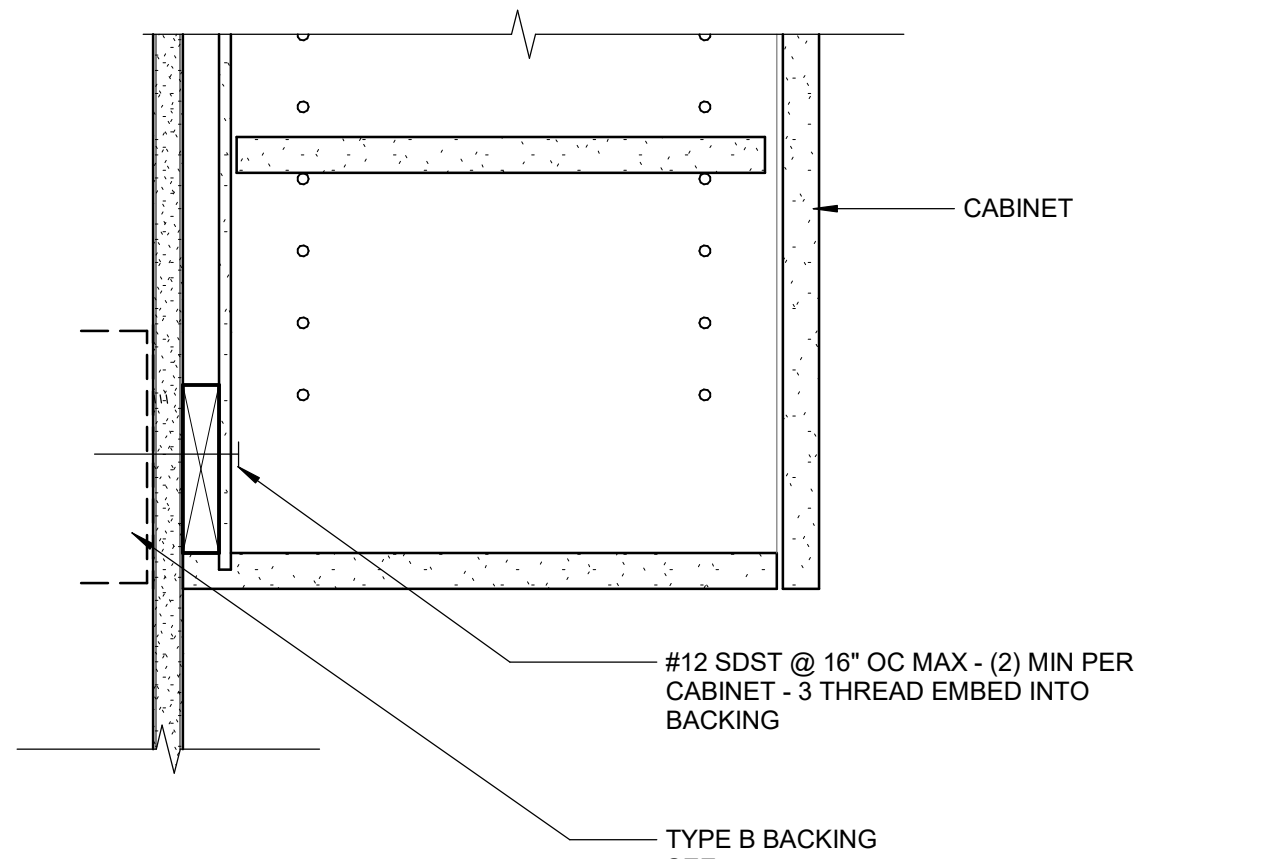


6 UPPER CASEWORK - TYP

3\"/>

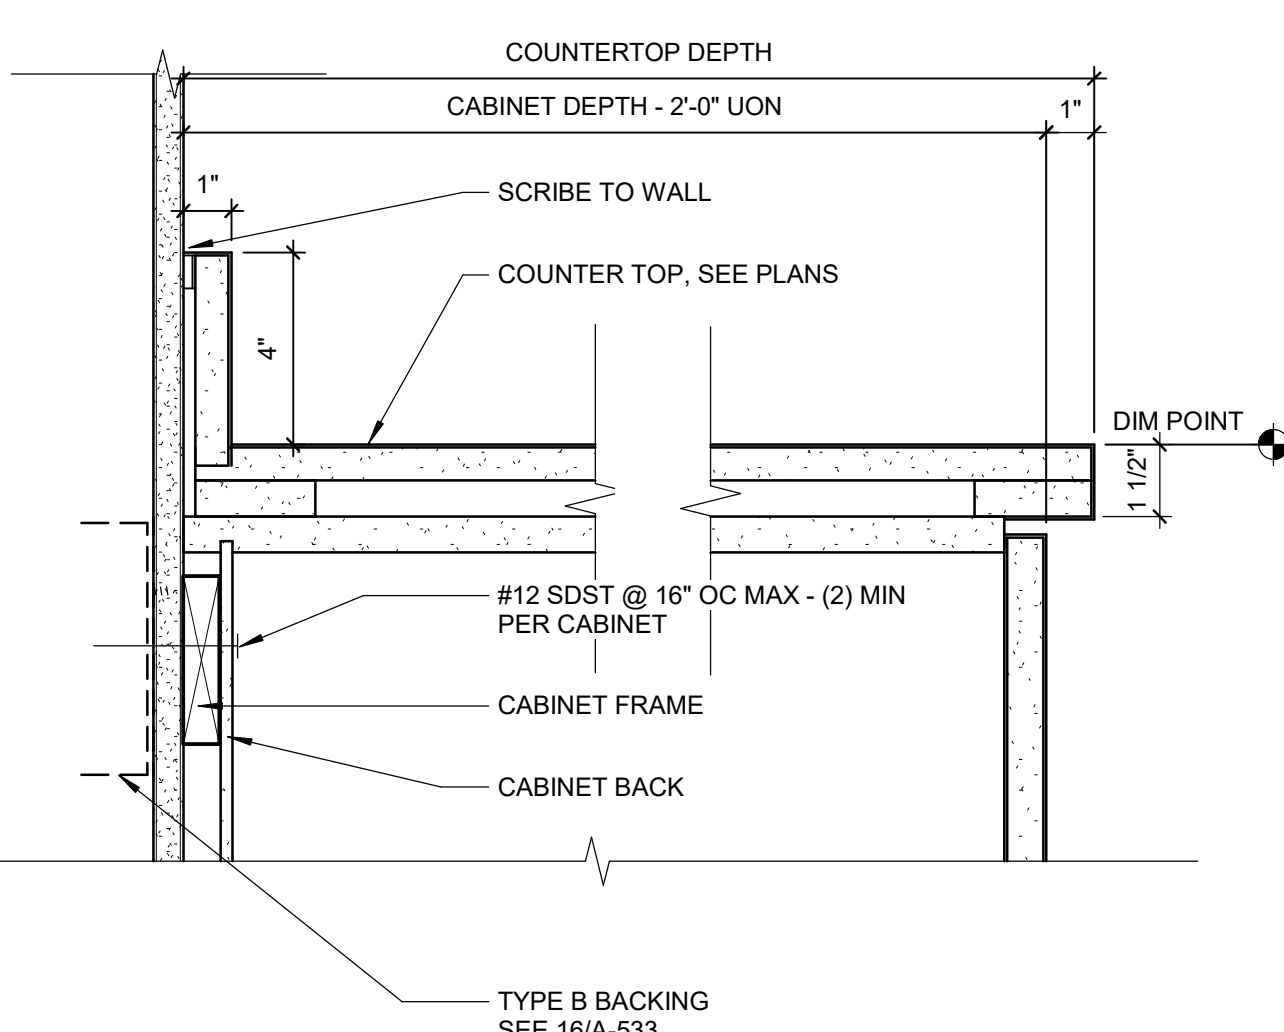


7 COUNTERTOP ANCHORAGE STEEL FRAMING

3\"/>

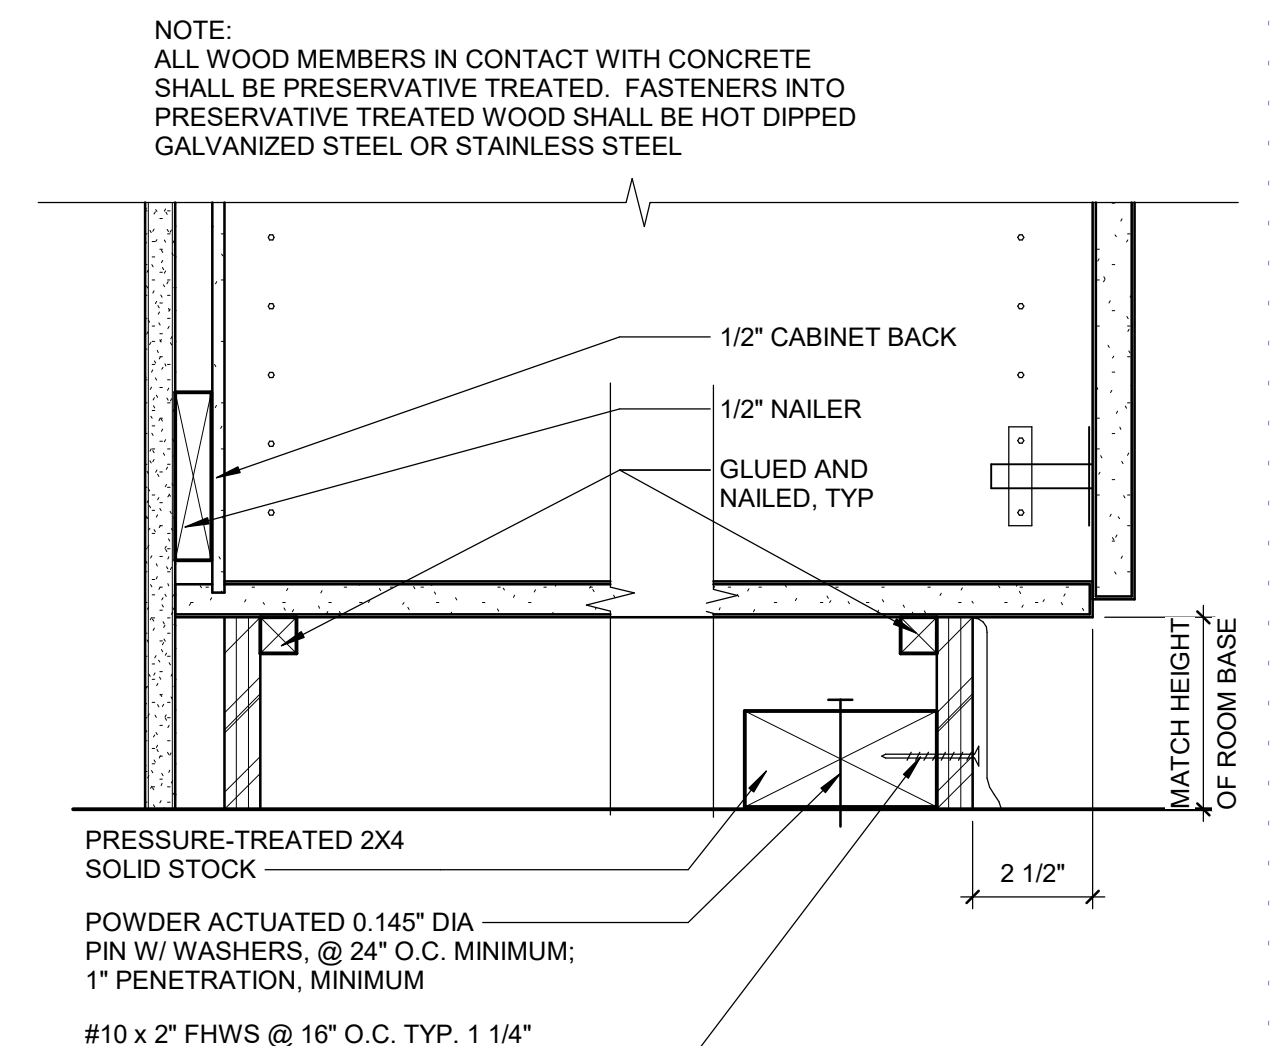


8 LOWER CASEWORK ANCHORAGE

3\"/>

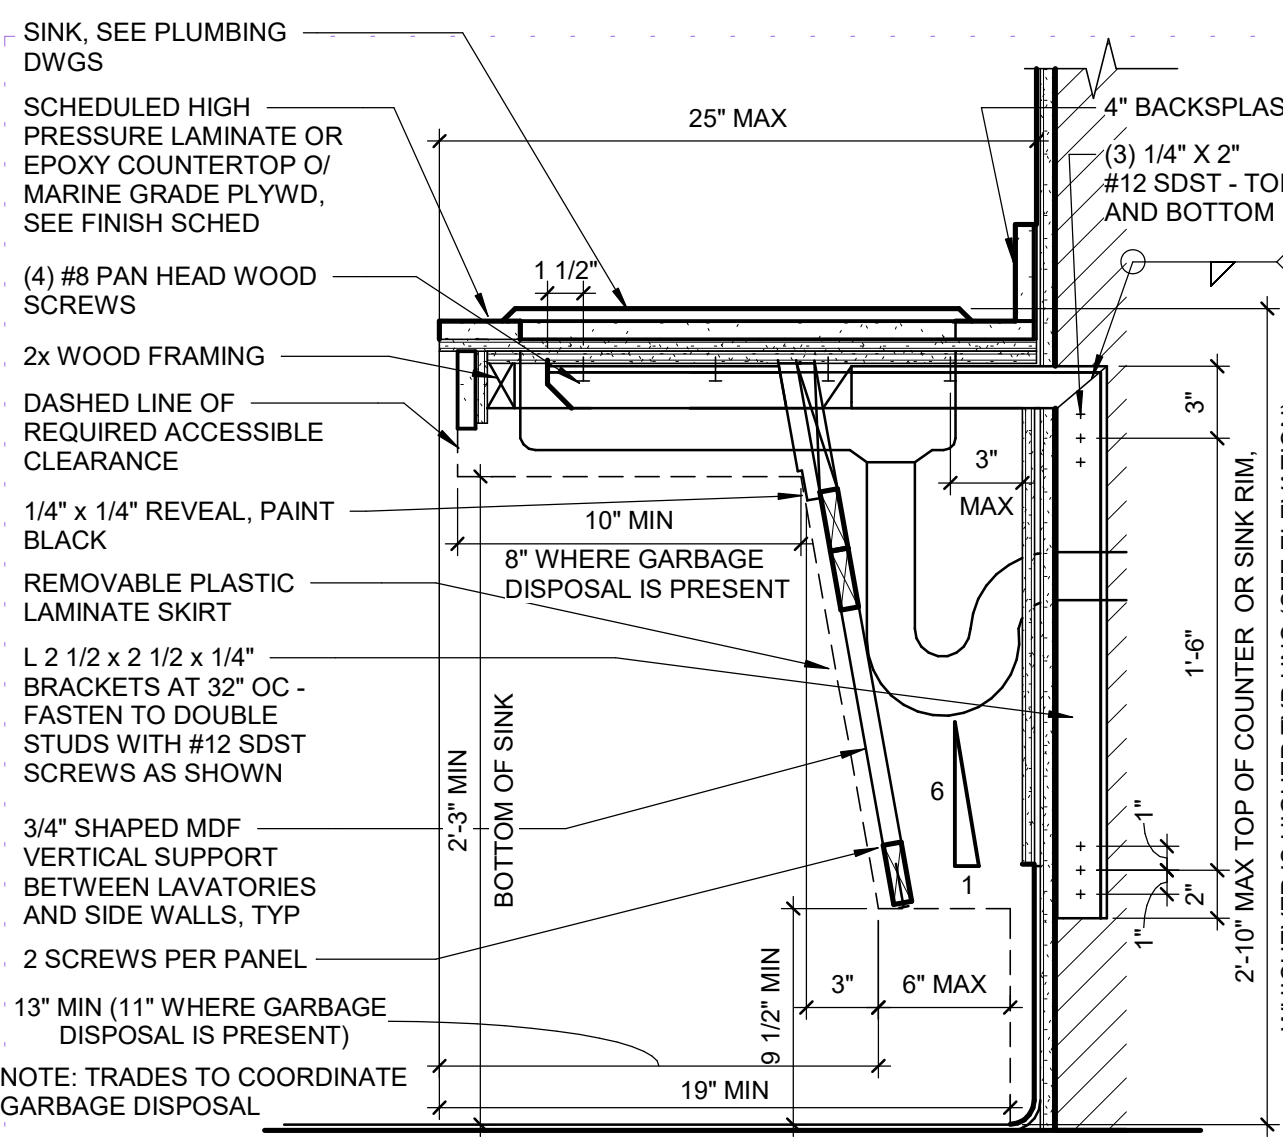


9 CASEWORK SKIRT SECTION W/ SINK AT P-LAM CONDITION

1 1/2\"/>

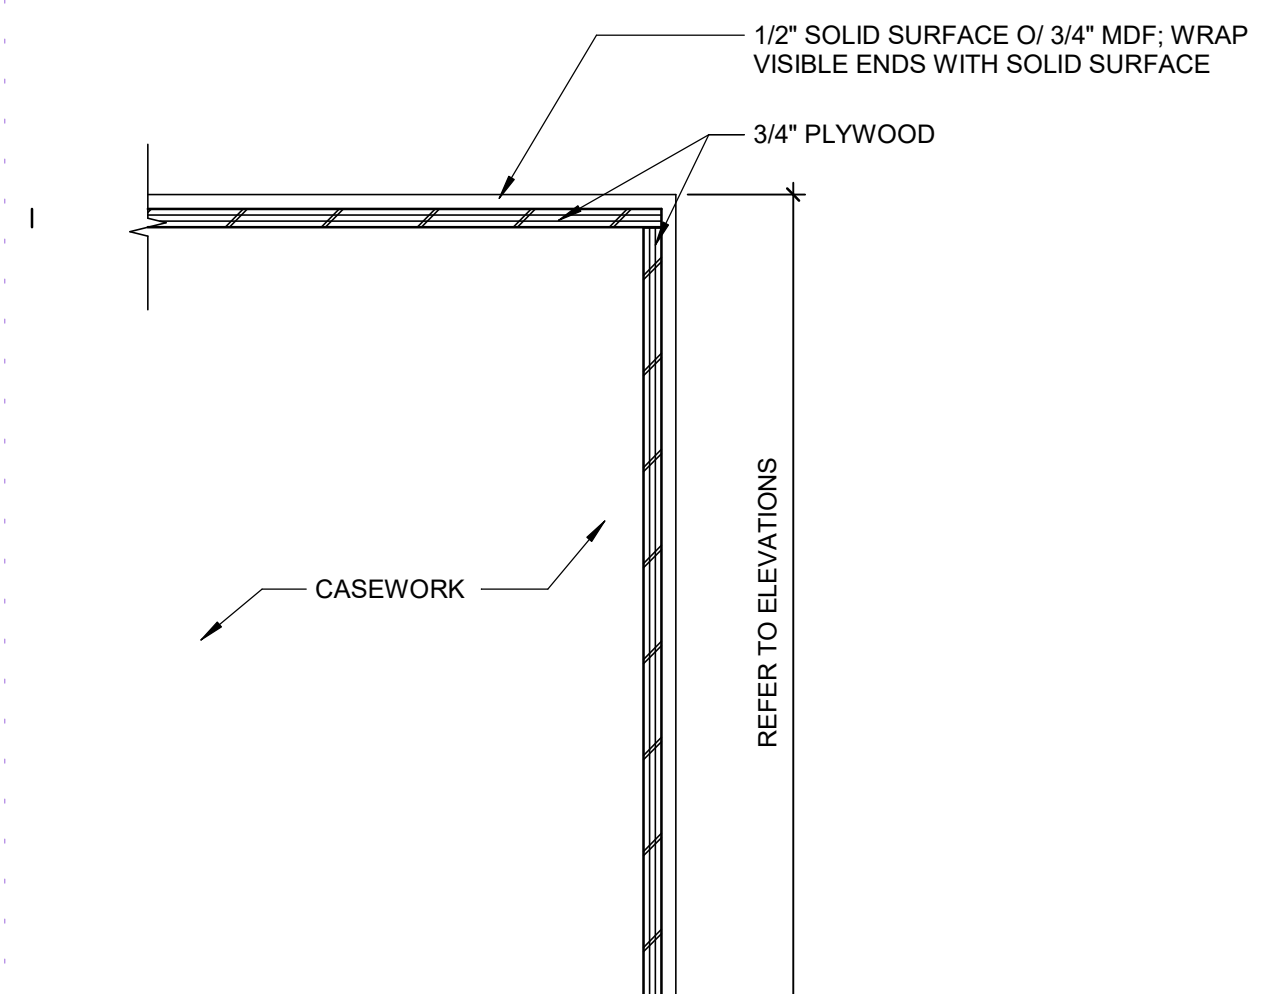


10 END PANEL

1 1/2\"/>

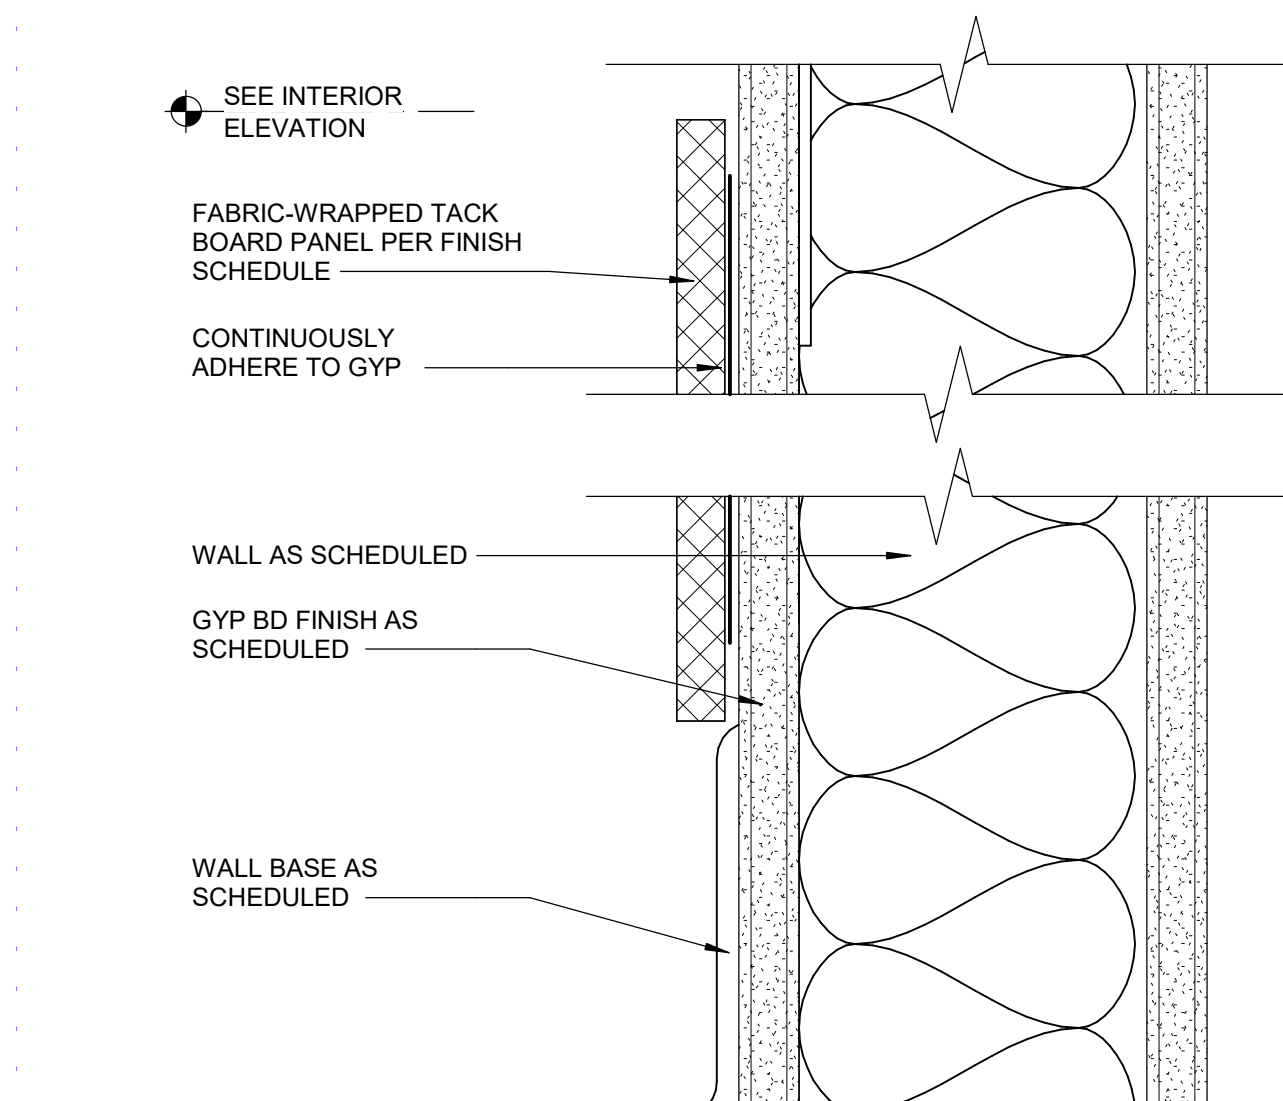


11 ADHESIVE-MOUNT TACK PANEL

6\"/>

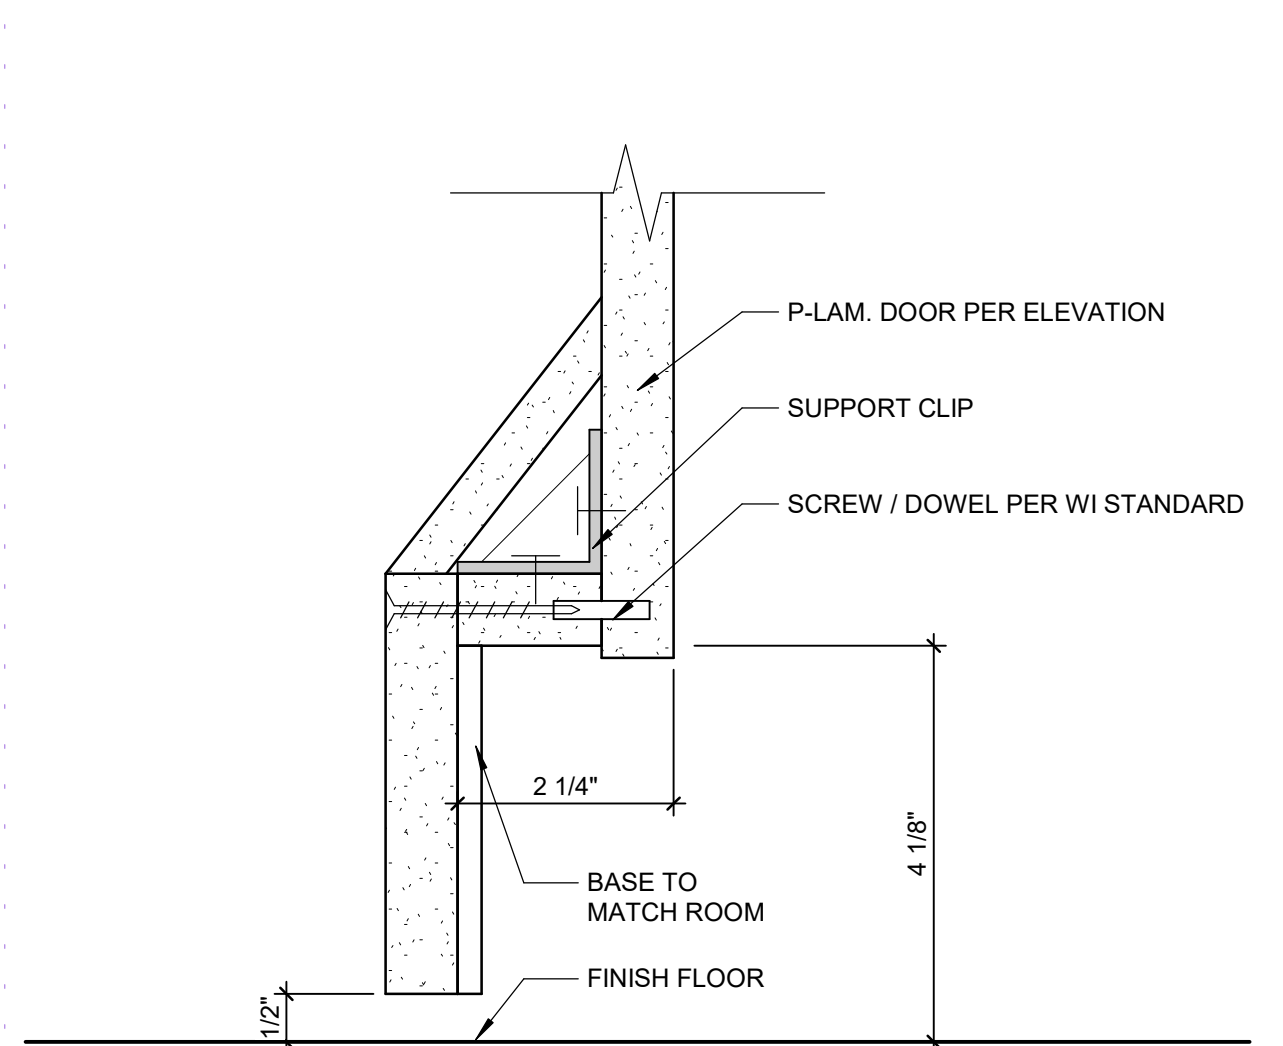


12 INTEGRAL TOE KICK

6\"/>

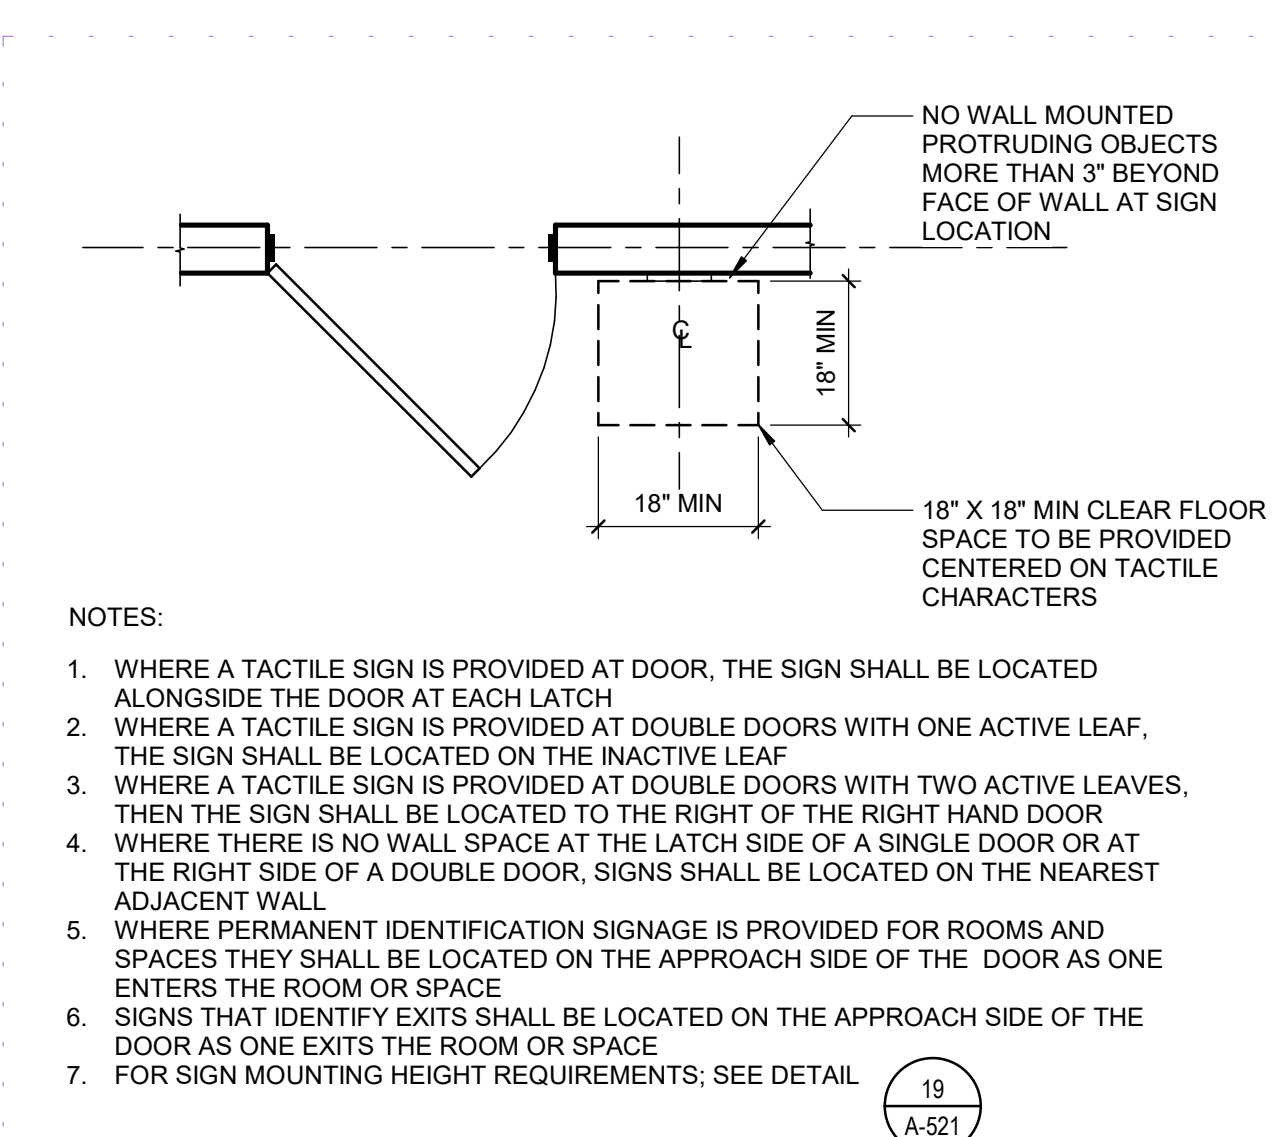


13 SIGN LOCATION

1 1/2\"/>

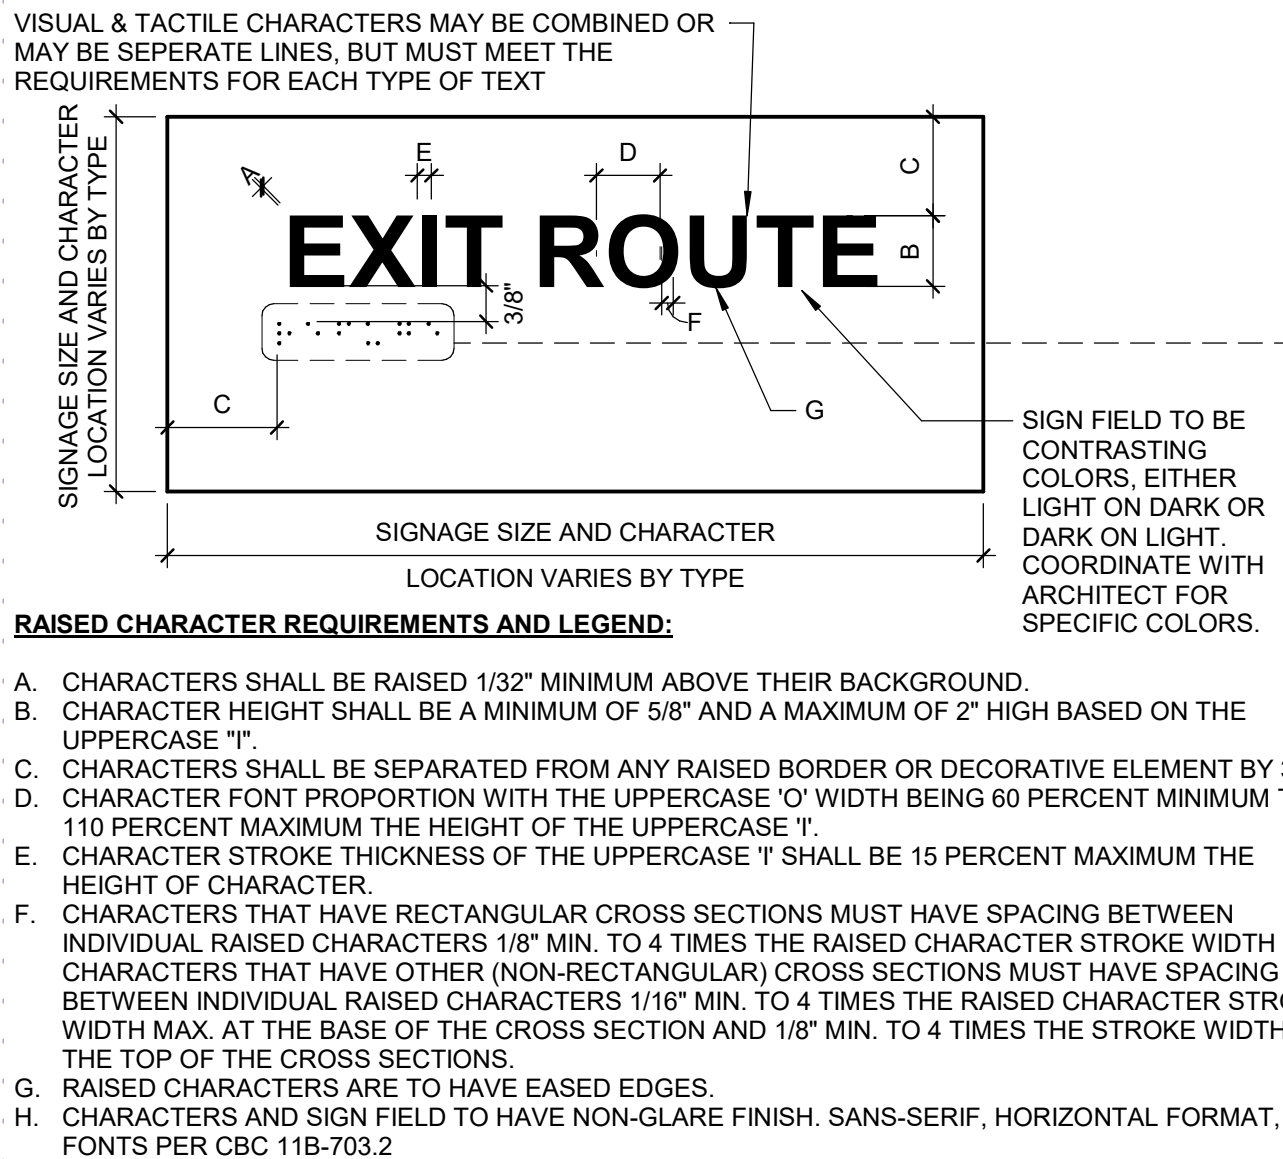


14 ACCESSIBLE TACTILE SIGN REQUIREMENTS

6\"/>

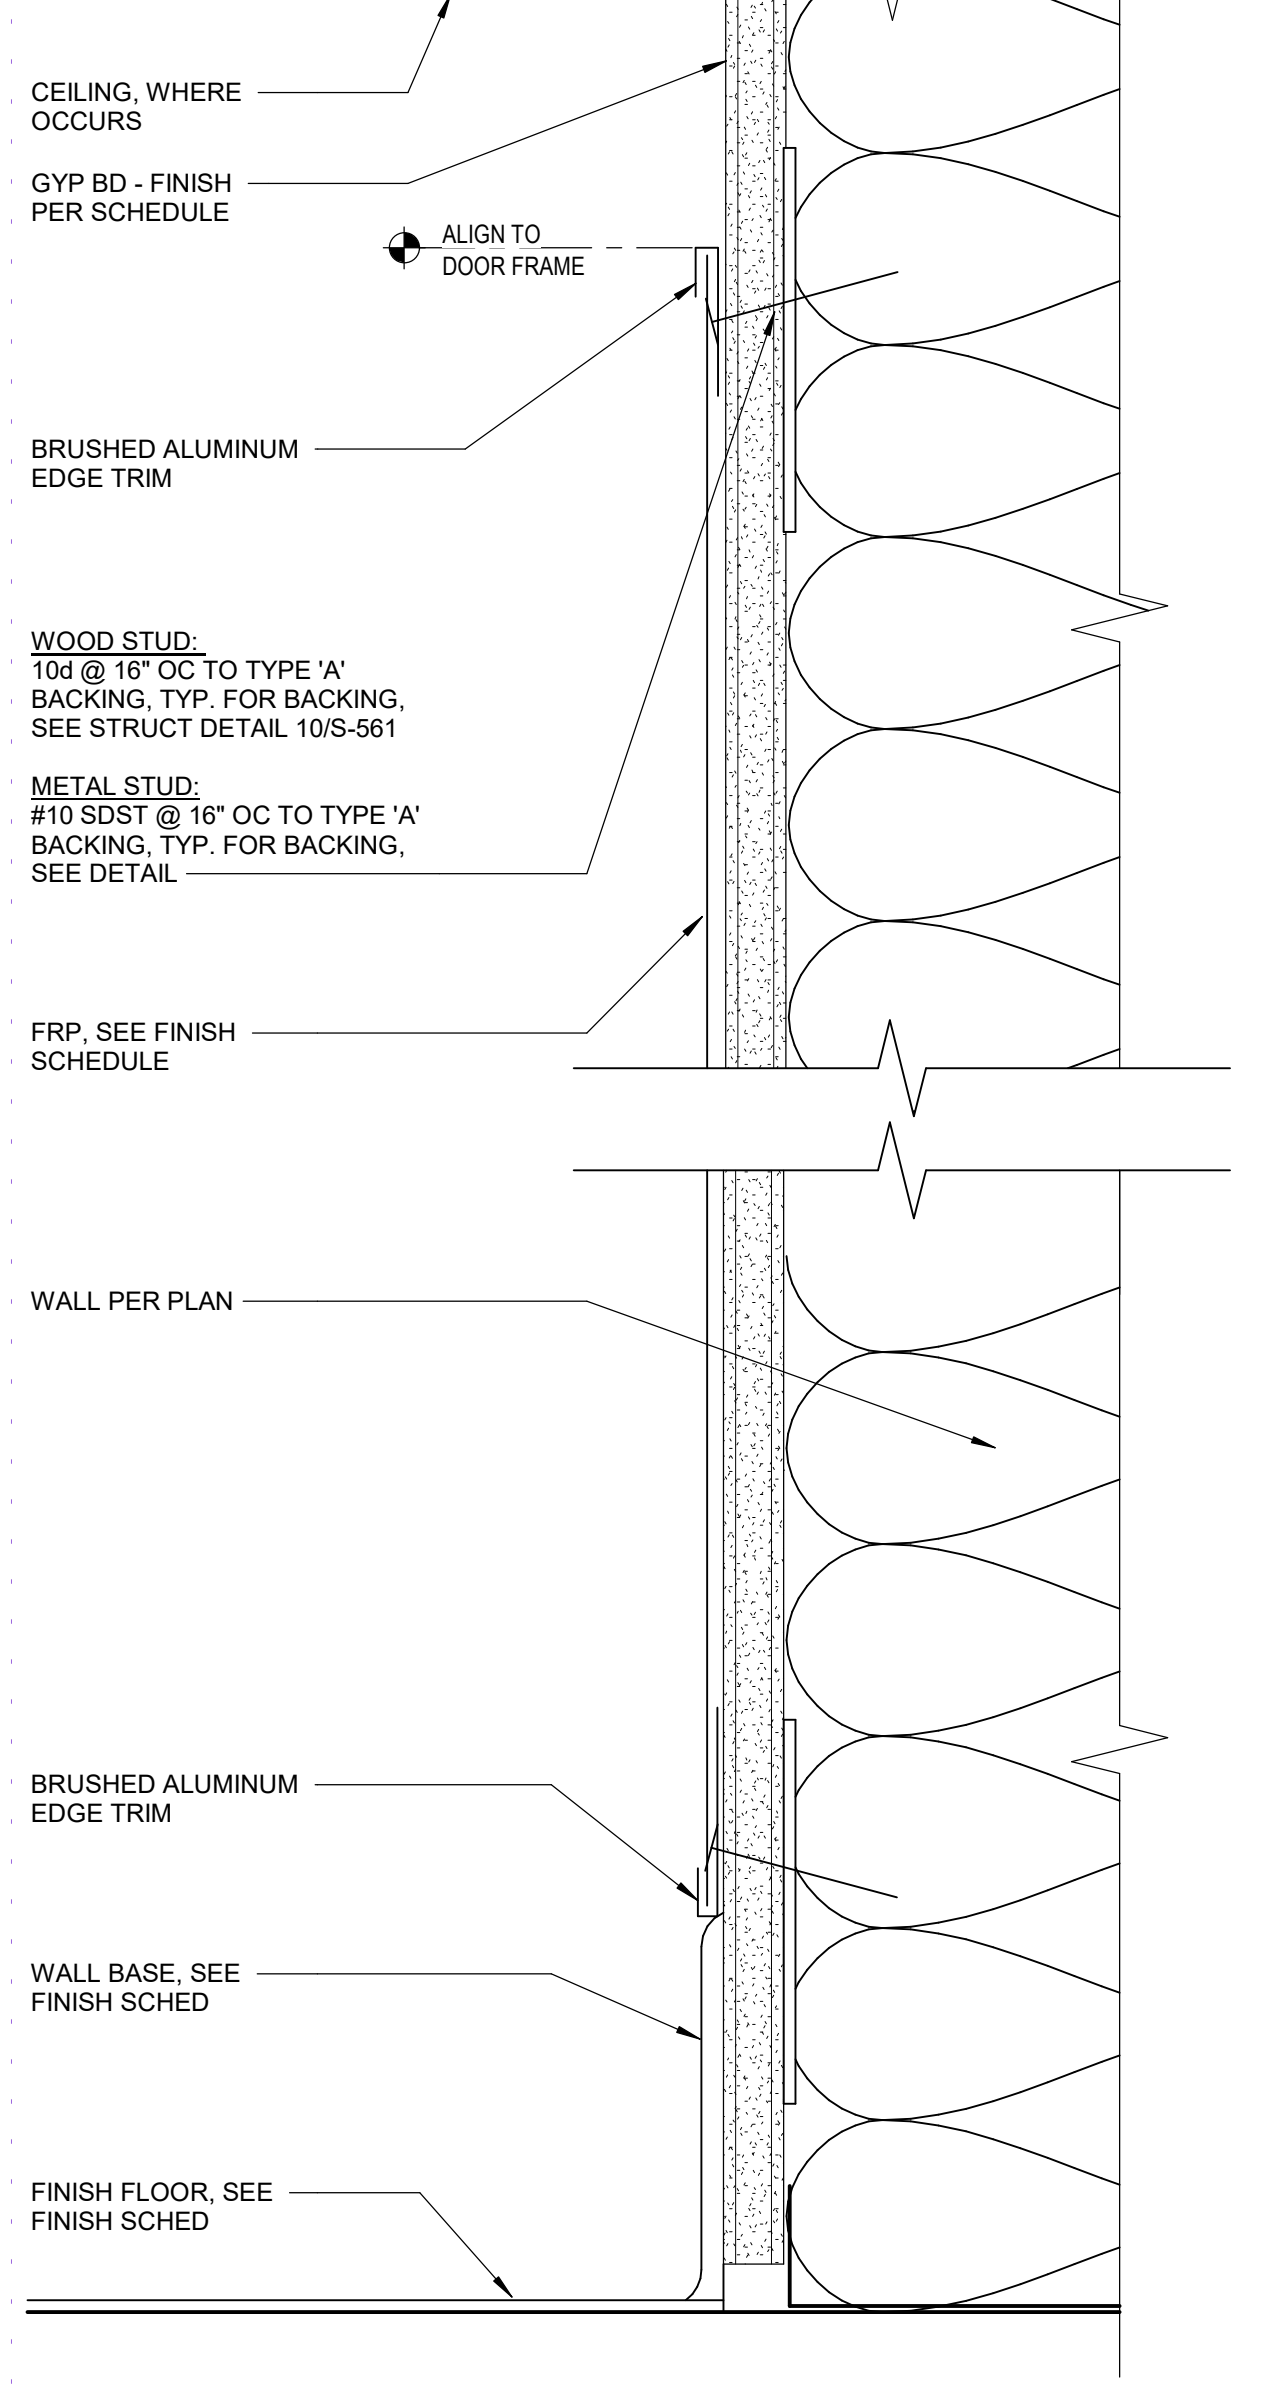


16 FRP TRIM

6\"/>

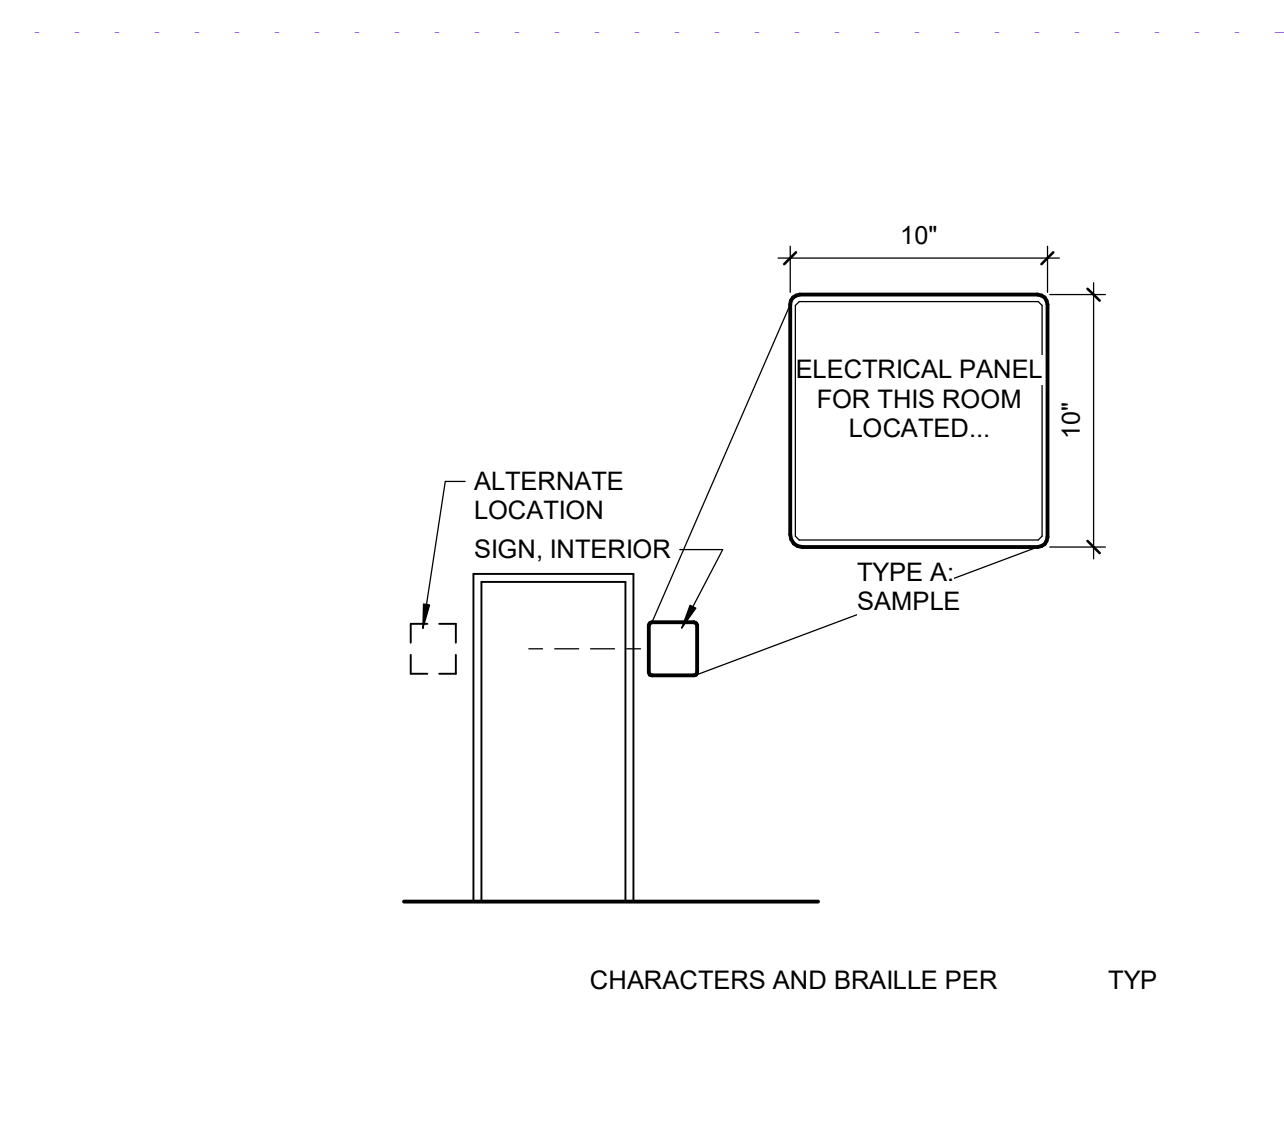


17 ELECTRICAL PANEL LOCATION SIGNAGE

18\"/>

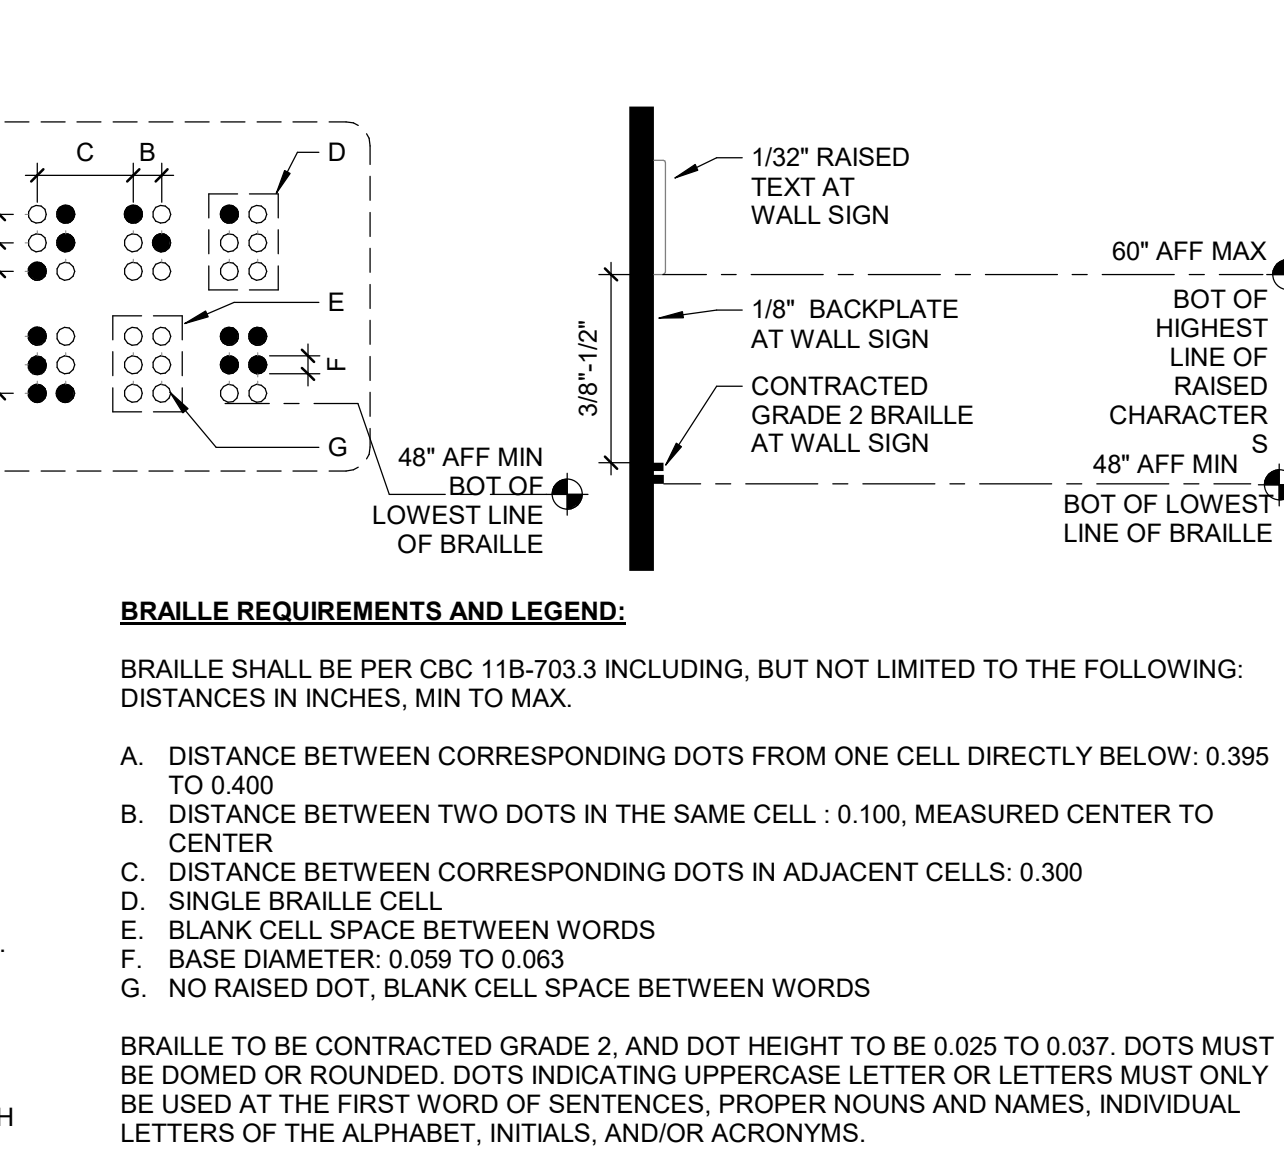

19 PERMANENT ROOM IDENTIFICATION SIGNS

1 1/4\"/>

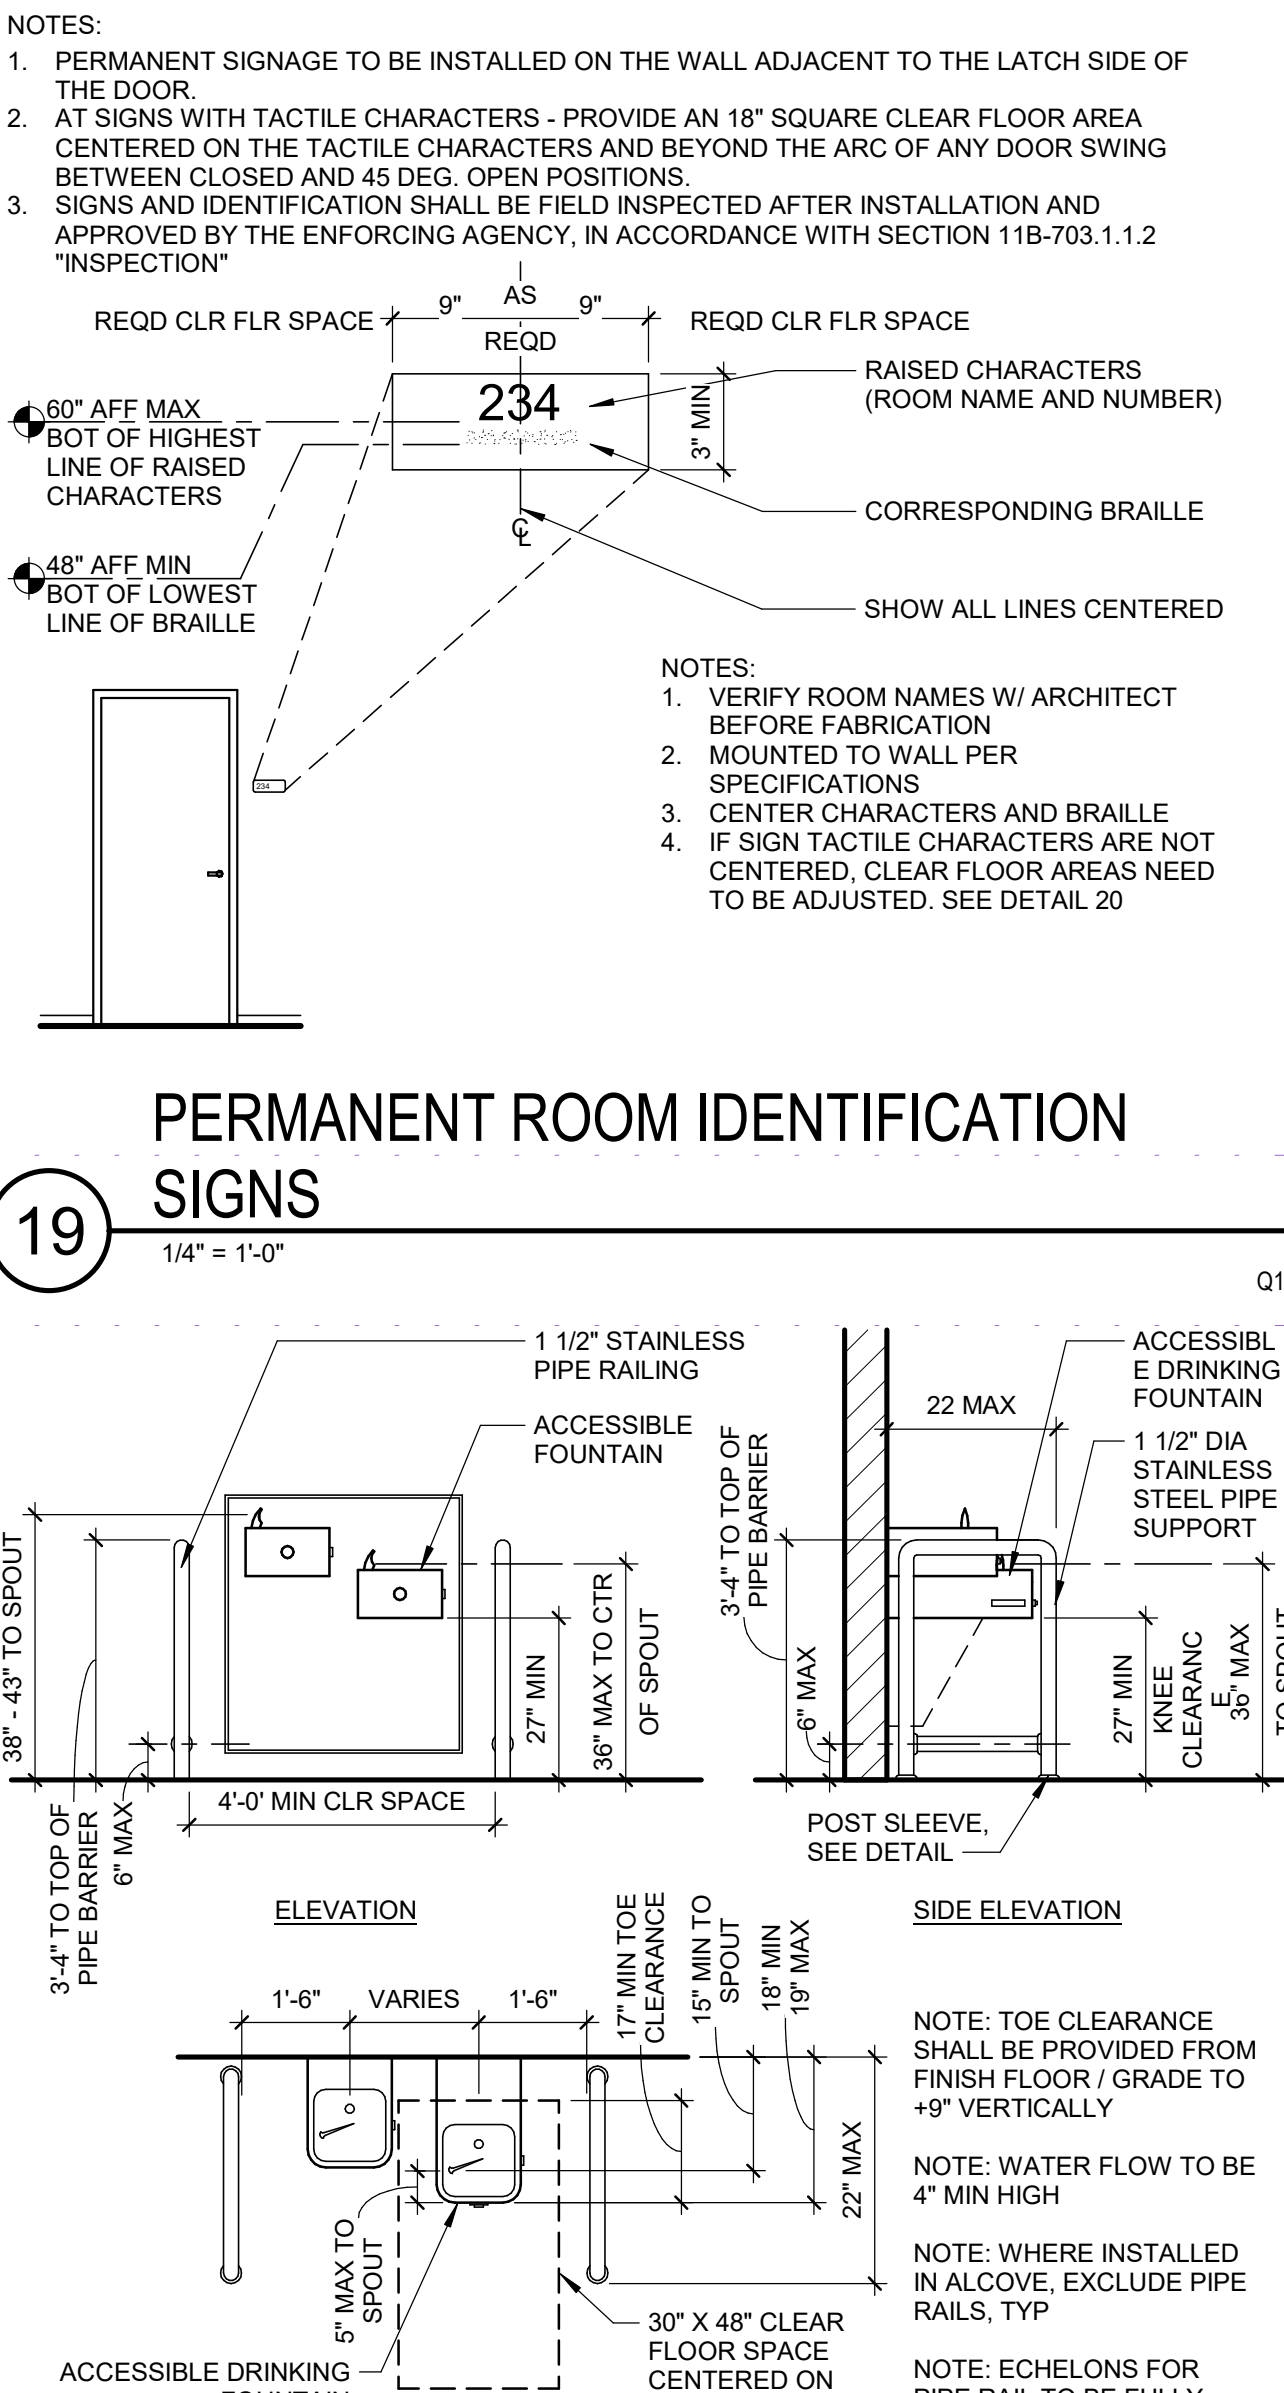


20 HI-LO DRINKING FOUNTAIN AT WALL

38\"/>

DOOR TYPES	FRAME TYPES
 Diagram of door type DF1. The door is shown in a side elevation view. It has a rectangular frame with a diagonal line indicating the door leaf. The height is labeled 'SEE SCHED' and the width is labeled 'SEE SCHED'. The door is labeled 'DF1' at the bottom left. A dashed line indicates the 'FIN FLR' (Finish Floor) level.	 Diagram of frame type FB1. The frame is shown in a side elevation view. It has a rectangular frame with a diagonal line indicating the door leaf. The height is labeled '7'-0" and the width is labeled '2" SEE SCHED 2"'. The frame is labeled 'FB1' at the bottom left. A dashed line indicates the 'FIN FLR' (Finish Floor) level.

1. GENERAL DOOR SHEET NOTES ARE TYPICAL UNLESS NOTED OTHERWISE.
2. FLOORS OR LANDINGS ON EACH SIDE OF EXIT DOORS SHALL NOT EXCEED 1/2" FROM THE TOP OF THE DOOR THRESHOLD TO THE FLOOR OR LANDING SURFACE ON EITHER SIDE OF THE DOOR ASSEMBLY.
3. EXITS AND EXIT ACCESS DOORS SHALL BE MARKED BY AN APPROVED EXIT SIGN READILY VISIBLE FROM AN ADJACENT TRAVEL WAY.
4. THE FORCE FOR PUSHING OR PULLING OPEN INTERIOR SWINGING EGRESS DOORS, OTHER THAN FIRE DOORS, SHALL NOT EXCEED 5 POUNDS. FOR OTHER SWINGING DOORS, AS WELL AS SLIDING AND FOLDING DOORS, THE FORCE SHALL NOT EXCEED 15 POUNDS WHEN SUBJECTED TO 15 POUND MAXIMUM FORCE.
5. LATCHING AND LOCKING DEVICES THAT ARE HAND ACTIVATED AND WHICH ARE IN THE PATH OF TRAVEL SHALL BE OPERABLE WITH A SINGLE EFFORT BY LEVER TYPE HARDWARE, PANIC BARS, PUSH-PULL ACTIVATING BARS OR OTHER HARDWARE DESIGNED TO PROVIDE PASSAGE WITHOUT REQUIRING THE USE OF A KEY OR ANOTHER MECHANISM.
6. THE BOTTOM 10" OF ALL DOORS EXCEPT AUTOMATIC AND SLIDING DOORS SHALL HAVE A SMOOTH UNINTERRUPTED SURFACE TO ALLOW THE DOOR TO BE OPENED BY A WHEELCHAIR USER WITHOUT THE NEED FOR A LATCH OR A HAZARDOUS CONDITION. WHERE NARROW FRAME DOORS ARE USED, A 10" HIGH SMOOTH PANEL SHALL BE INSTALLED ON THE PUSH SIDE OF THE DOOR, WHICH WILL ALLOW THE DOOR TO BE OPENED BY A WHEELCHAIR FOOTREST.
7. ALL DOORS CREATING A TRIP OR FALL HAZARD SHALL BE SELF-CLOSING.
8. FIRE RATED DOORS AND GLASS SHALL HAVE AN APPROVED LABEL OR LISTING MARK WHERE FABRICATION AND ASSEMBLY OCCUR.
9. DOOR FRAME ASSEMBLY DIMENSIONS SHALL BE FIELD VERIFIED PRIOR TO FABRICATION AND INSTALLATION.
10. COORDINATE OVERALL DOOR FRAME DEPTHS WITH WALL TYPES.
11. DOOR HARDWARE GROUP SHALL BE IDENTIFIED BY SPECIFICATIONS.
12. FOR SIGNAGE LOCATIONS, SEE SIGNAGE PLANS.
13. FOR SIGNAGE ON OR ADJACENT TO DOORS, SEE SHEET SERIES G-100.
14. FOR GLASS PARTS, COORDINATE WITH THE GLASS DESIGN OF THE FLOOR OR WITHIN 24" HORIZONTALLY OF ANY DOOR OPENING SHALL BE FULLY TEMPTEED GLASS APPROVED FOR IMPACT HAZARD.
15. PROVIDE A REINFORCED GLASS AT RATED DOORS AND FRAMES WITH LITES. SEE DOOR SCHEDULE AND PROJECT SPECIFICATIONS.
16. COORDINATE THE SIZE AND LOCATION OF RECESSES IN CONCRETE FLOORS FOR RECESSES FOR HAND RAILWAYS.
17. SEE SECURITY DRAWINGS FOR DOORS WITH CARD READERS AND OTHER SECURITY DEVICES. COORDINATE WITH THE SECURITY DESIGN OF THE FLOOR OR WITHIN 24" HORIZONTALLY OF ANY DOOR OPENING SHALL BE FULLY TEMPTEED GLASS APPROVED FOR IMPACT HAZARD.
18. HOLLOW METAL FRAMES IN MASONRY CONSTRUCTION SHALL BE GROUTED FULL.

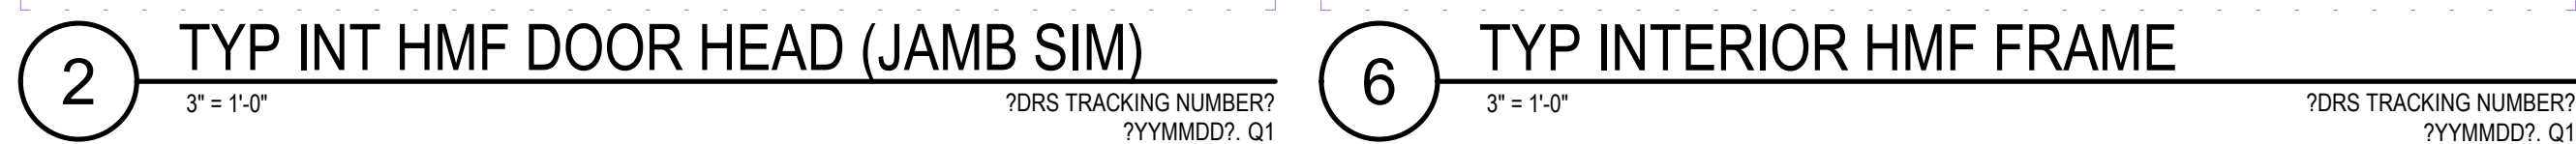

(E) = EXISTING	MATERIAL
ADD = AUTOMATIC DOOR OPERATOR	ALUM = ALUMINUM
ADD = AUTOMATIC DOOR CLOSER	DHM = DETENTION HOLLOW METAL
RF = CARD READER	HM = HOLLOW METAL
EL = ELECTRIC LOCK	SST = STAINLESS STEEL
HOW GP = HARDWARE GROUP	WD = WOOD
HO = HOLD OPEN	
PH = PANIC HARDWARE	FINISH
V = VINYL STRIPS	ANOD = ANODIZED
	FRP = FIBER REINFORCED PLASTIC
<u>GLASS LEGEND:</u>	PLAM = PLASTIC LAMINATE
GL = GLASS	PT = PAINT
LG = LEADED GLASS	TS = STAIN
RG = RATED GLASS	
SG = SPANDREL GLASS	
TG = TEMPERED GLASS	
<u>GLASS LEGEND NOTES:</u>	
1. SEE SPECS FOR GLASS TYPES NOTED	

```

graph TD
    DT[DOOR TYPE] --> D[D = DOOR]
    DT --> S[S = SLIDER]
    D --> DC[DOOR CONFIGURATION]
    D --> VV[VERSION VARIATION]
    DC --> F[F = FLUSH]
    DC --> G[G = GLASS]
    DC --> V[V = VISION]
    DC --> L[L = LOUVER]
    DC --> D2[D = DUTCH]
    DC --> J[J = DETENTION]
    DC --> S2[S = SLIDER]
    DC --> O[O = OVERHEAD]
    DC --> C[C = COUNTER]
    DC --> A[A = ACCORDION]
    DC --> P[P = STRIP CURTAIN]
    VV --> V1[1 = VERSION 1]
    VV --> V2[2 = VERSION 2]
    VV --> ETC[ETC.]
  
```

DOOR TYPE
D = DOOR
S = SLIDER

DOOR CONFIGURATION
F = FLUSH
G = GLASS
V = VISION
L = LOUVER
D = DUTCH
J = DETENTION
S = SLIDER
O = OVERHEAD
C = COUNTER
A = ACCORDION
P = STRIP CURTAIN

CONFIGURATION VERSION
1 = VERSION 1
2 = VERSION 2
ETC.

VERSION VARIATION
A = VARIATION A
B = VARIATION B
ETC.

The diagram illustrates the structure of the code 'FR1M' by mapping its characters to specific product options. Lines connect the characters to their corresponding descriptions:

- F** connects to **FRAME PROFILE (AT DOOR ONLY)**
 - F** = DOUBLE RABBIT (TYP)
 - R** = SINGLE RABBIT
 - E** = DOUBLE EGRESS
 - C** = CASED
 - P** = POCKET
- R** connects to **FRAME CONFIGURATION**
 - B** = BASIC THREE-SIDED
 - T** = TRANSOM
 - G** = GLASS LITE
 - V** = VISION LITE
 - W** = TRANSOM W/ GLASS LITE
 - X** = TRANSOM W/ VISION LITE
 - J** = DETENTION
 - P** = PARTIAL TWO-SIDED
 - Q** = FOUR-SIDED
- 1** connects to **CONFIGURATION VERSION**
 - 1** = VERSION 1
 - 2** = VERSION 2
 - ETC.
- M** connects to **VERSION VARIATION**
 - A** = VARIATION A
 - M** = VARIATION W/ MULLION
 - R** = VARIATION W/ REMOVABLE MULLION
 - ETC.

The final code **FR1M** is shown at the bottom left, with the letters **F**, **R**, **1**, and **M** aligned under their respective category headers.



3066 FREEPORT BLVD
SACRAMENTO, CA 95818

5735 47TH AVE, SACRAMENTO CA 95824

ISSUED

MARK	DATE	DESCRIPTION
------	------	-------------

MANAGEMENT

LIONAKIS PROJECT NO: 026031

COPYRIGHT: LIONAKIS 2011

TITLE

SCHEDULES / DIAGRAMS - DOORS

SHEET

A-621

ROOM FINISH SCHEDULE																						
NO	ROOM NAME	FLOOR			NORTH			EAST			SOUTH			WEST			CEILING		CASEWORK TYPE	WINDOW COVERING	INTERIOR ELEVATION	INTERIOR FINISH REMARKS
		MATL	FIN	BASE	MATL	FIN	BASE	MATL	FIN	BASE	MATL	FIN	BASE	MATL	FIN	BASE	MATL	FIN				
223	TRAINING	E	SP1	E	5	SP2,P1	5	SP2,P1	5	SP2,P1	5	SP2,P1	5	SP2,P1	5	P1	TYPE 1				REPAIR EXISTING FLOORING AND TOPOCOAT ENTIRE AREA	
224	STOR		RT1	B1	5	E	5	E	5	E	5	E	5	OTS	-						FLOORING TO BE REPLACED IN KIND	
230	VEST	E	SP1	E	5	E	5	E	5	E	5	E	5	P1	5	P1					REPAIR EXISTING FLOORING AND TOPOCOAT ENTIRE AREA	

INTERIOR FINISH LEGEND			
FINISH CODE	MANUFACTURER	TYPE / STYLE, COLOR, SIZE	NOTES
RESILIENT TILE			
RT1		PATTERN: TBD, COLOR: TBD	
PAINT			

P1		MATCH EXISTING	FIELD WALL PAINT
BASE			
B1	BURKE	4" COVE RUBBER BASE; COLOR: TBD	GENERAL WALL BASE
PLASTIC LAMINATE			
PL1	FORMICA	COLOR: TBD	TRAINING ROOM CASEWORK
SOLID SURFACE			
SS1	CORIAN	SOLID SURFACE. COLOR: TBD	TRAINING ROOM COUNTER
SPECIALTY PRODUCTS AND FINISHES			
SP1		EPOXY FLOORING, MATCH EXISTING	
SP2	MARLITE	FRP; COLOR: TBD	WALL PROTECTION

CASEWORK LEGEND AND NOTES

NOTES

1. CASEWORK TO BE TYPE 1, UNO
2. PROVIDE CASEWORK LOCKS AS NOTED ON THE INTERIOR ELEVATIONS. (COORDINATE CASEWORK LOCKS, QUANTITY AND LOCATION WITH OWNER)
3. PROVIDE GROMMETS @ ALL KNEE SPACES. COLOR XY/TB. LOCATIONS TBD WITH ARCHITECT IN FIELD.
4. ALL CASEWORK SHELVING SHALL BE ADJUSTABLE, UNO.
5. PLASTIC LAMINATE DUST CAPS TO MATCH ADJACENT VERTICAL LAMINATE, UNO.
6. COUNTER EDGE BANDING TO BE 3 MIL GREENLINE ABS EDGE BANDING, TO MATCH HORIZONTAL SURFACE.
7. DRAWER AND DOOR EDGE BANDING TO BE 3 MIL EDGE BANDING TO MATCH VERTICAL SURFACE.
8. ALL CASEWORK SHALL MEET KAISER CASEWORK STANDARDS/ ALL CASEWORK MUST MEET W/ CUSTOM CASEWORK STANDARD CERTIFICATION.

TYPE 1

HORIZONTAL: PL1 VERTICAL: SS1 BASE: USE BASE SPECIFIED IN ROOM (STANDARD UPPERS AND LOWERS) (TYPICAL UNO)

GENERAL NOTES

1. IF AT ANY TIME THE GENERAL CONTRACTOR REQUIRES CLARIFICATION OF FINISH LOCATIONS, CONTACT PROJECT ARCHITECT PRIOR TO FINISH APPLICATION.
2. PATCH AND REPAIR ALL WALLS WITHIN SCOPE, PREP FOR NEW WALL FINISH.
3. CLEAN AND PAINT EXISTING EXPOSED CONDUIT, DIFFUSERS, AND ACCESS PANELS TO MATCH ADJACENT WALL.
4. PAINT DOORS AND DOOR FRAMES WITHIN SCOPE TO MATCH ADJACENT WALL.
5. PROTECT ALL (E) BUILT IN ELEMENTS TO REMAIN PRIOR TO PAINTING
6. ALL FLOORS AND WALL BASE WITHIN SCOPE TO BE PATCHED AND REPAIRED TO MATCH IN KIND U.N.O.
7. REPLACE ALL DEVICE/OUTLET PLATES TO MATCH.

INTERIOR FINISH REMARKS	
1.	SEE REFLECTED CEILING PLAN FOR CLARIFICATION ON CEILING TYPES AND FINISH.
2.	SEE INTERIOR ELEVATIONS FOR FINISH CLARIFICATION AND LOCATION.
3.	PAINT ELECTRICAL PANEL DOORS AND FIRE EXTINGUISHER CABINETS TO MATCH ADJACENT WALL UNO.
4.	FLOORING AND COVERED BASE SHALL HAVE WELDED SEAMS TO MATCH DARKEST ADJACENT FLOORING

MATERIAL CODES	
1	CONCRETE
2	PLYWOOD (DECKING)
3	CONCRETE MASONRY UNIT
4	BRICK
5	GYPSUM WALLBOARD
6	GYPSUM WALLBOARD, WATER RESISTANT
7	EXPOSED STRUCTURE
8	CEMENTITIOUS WALLBOARD
E	EXISTING
OTS	OPEN TO STRUCTURE



2025 Nineteenth Street
Sacramento CA 95811
P 916.558.1900
www.lionakis.com

CONSULTANT

SEAL



PROJECT
MCCLATCHY HS TRAINING ROOM

3066 FREEPORT BLVD
SACRAMENTO, CA 95818

CLIENT
SACRAMENTO CITY UNIFIED SCHOOL DISTRICT

5735 47TH AVE, SACRAMENTO CA 95824

ISSUED

MARK	DATE	DESCRIPTION
------	------	-------------

MANAGEMENT

LIONAKIS PROJECT NO: 026031




COPYRIGHT: LIONAKIS 2011

TITLE

INTERIOR FINISH LEGEND AND SCHEDULE

SHEET

A-641

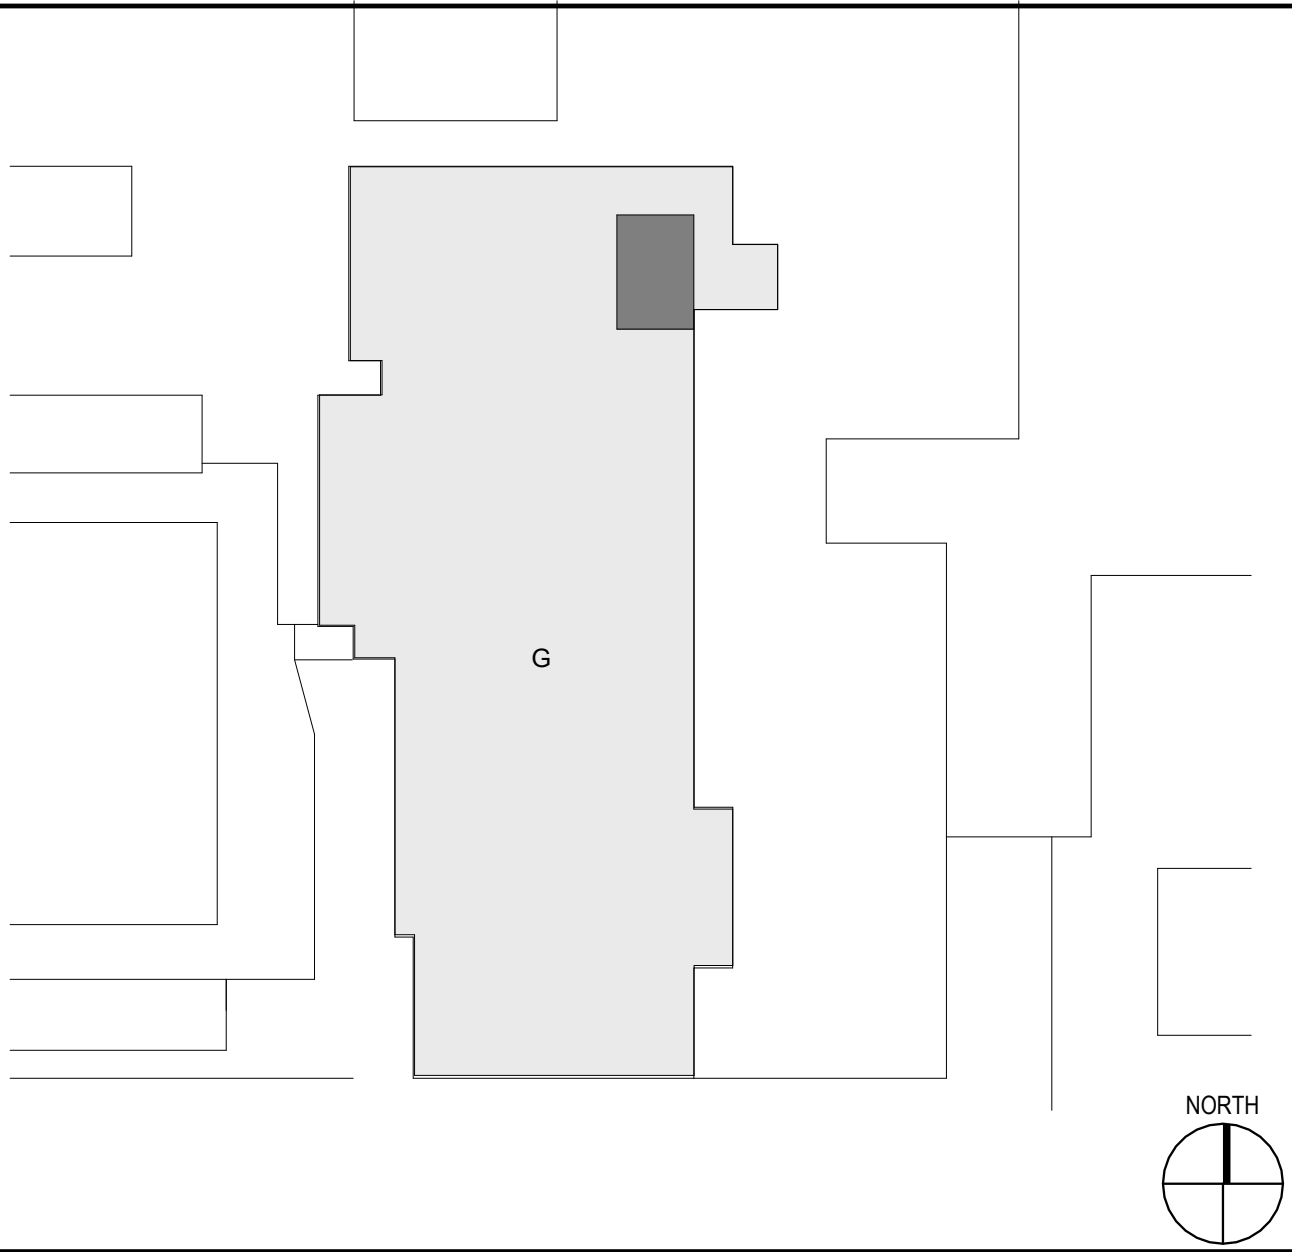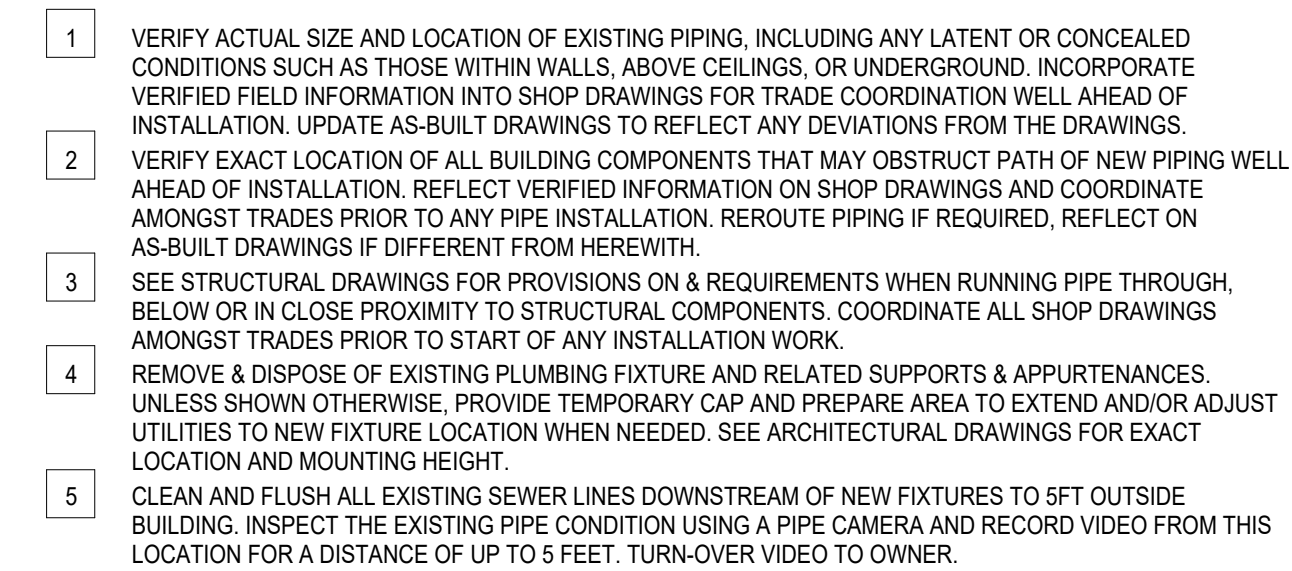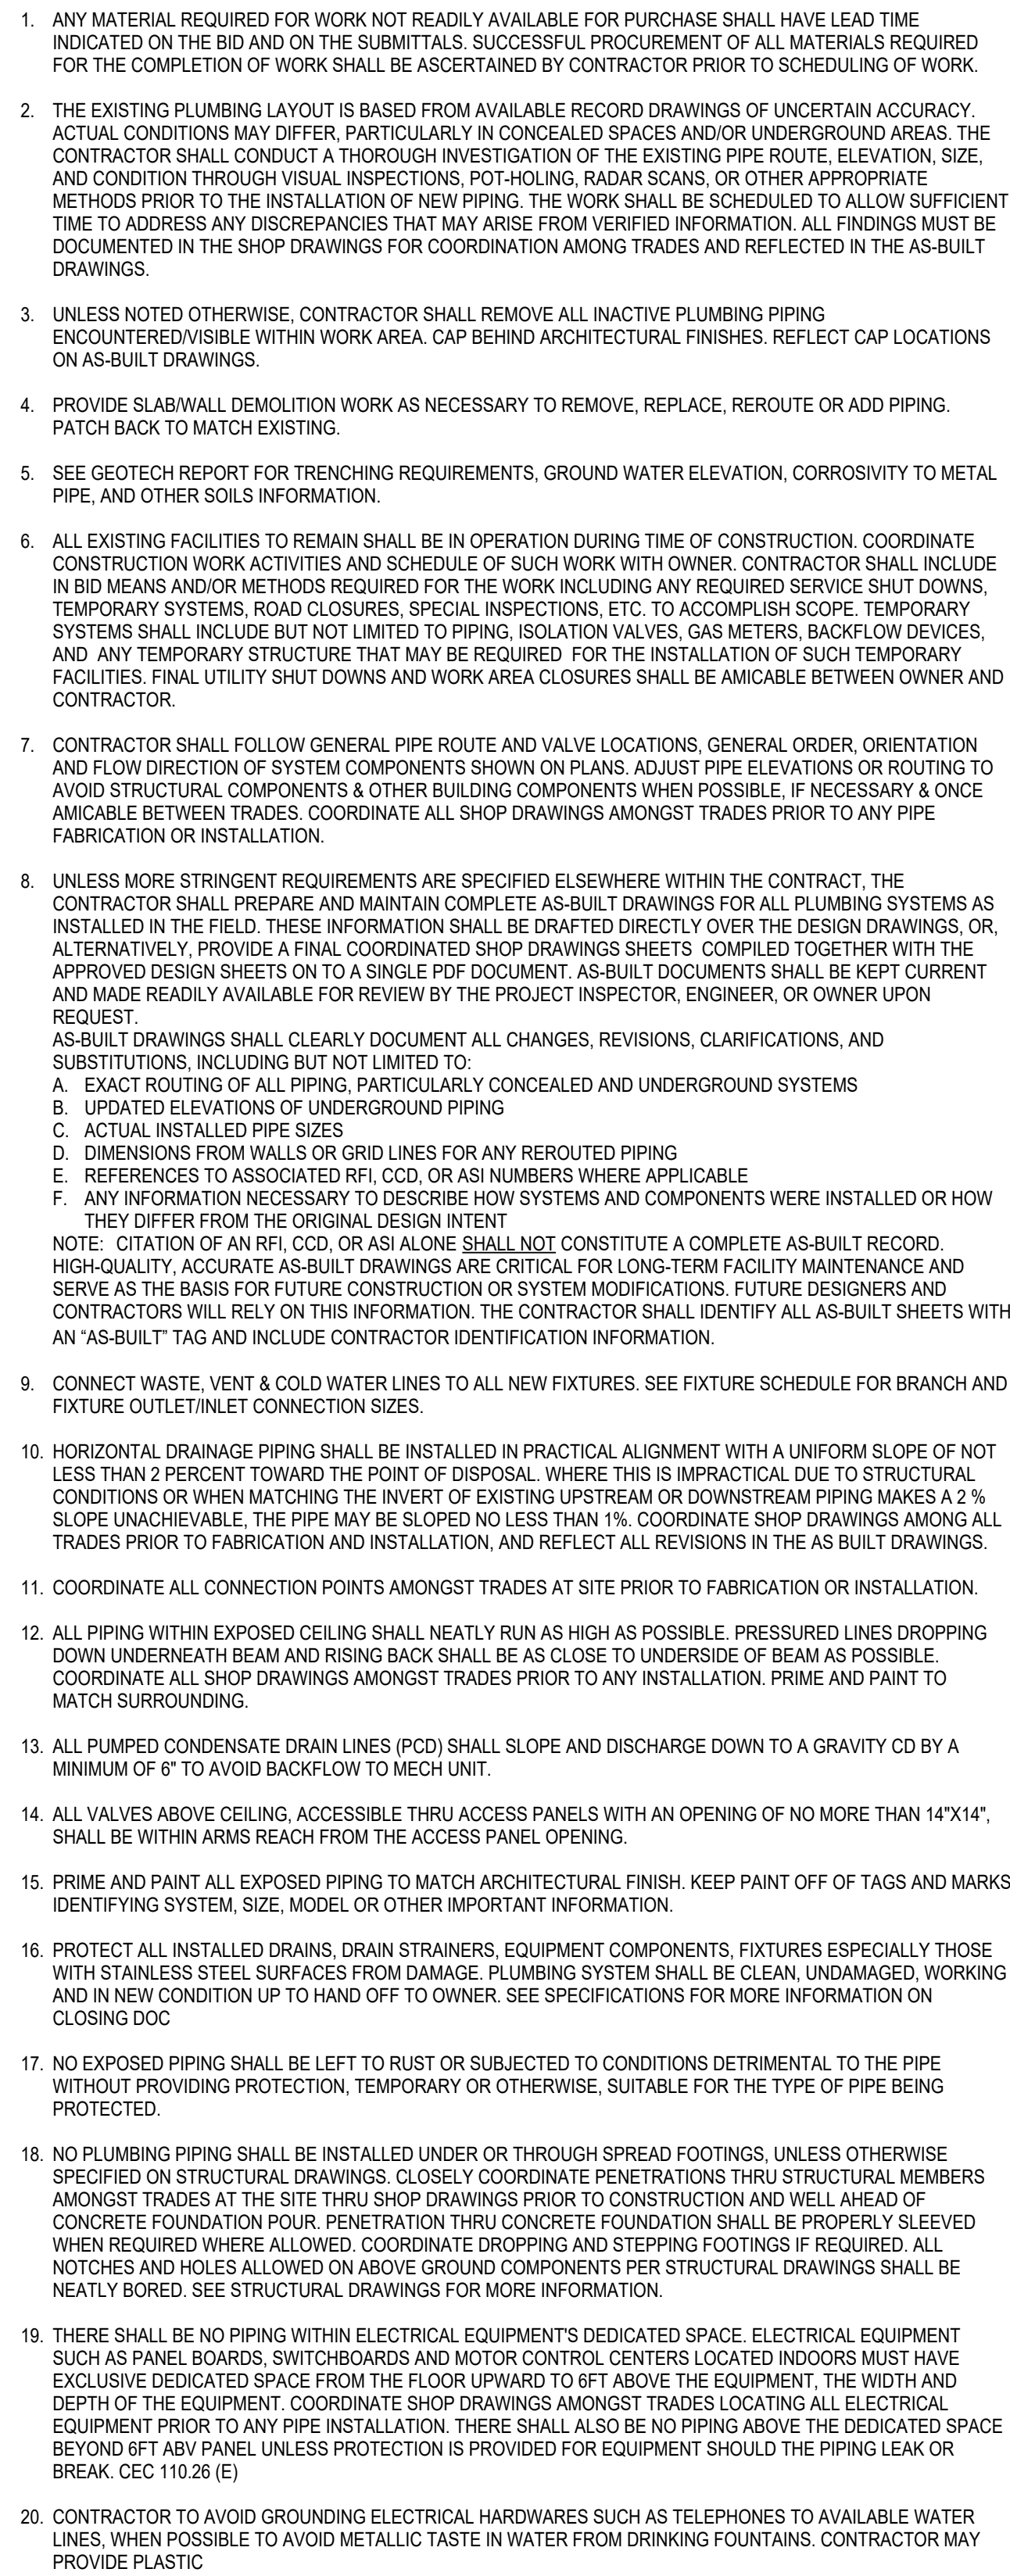

CAPITAL
engineering
RANCHO CORDOVA, CALIFORNIA
KS-MB/JV 260241.00
PM - DESIGN TEAM PROJECT NO.

5735 47TH AVE, SACRAMENTO CA 95824

ISSUED		
MARK	DATE	DESCRIPTION

LIONAKIS PROJECT NO: 02603
COPYRIGHT: LIONAKIS 2017

PD111

PROJECT GENERAL NOTES

"GENERAL NOTES"

1. ELECTRICAL SCOPES SHALL COMPLY WITH THE LATEST ADOPTED EDITIONS OF THE CALIFORNIA ELECTRIC CODE (CEC), CALIFORNIA BUILDING CODE (CBC), CALIFORNIA FIRE CODE (CFC), CALIFORNIA MECHANICAL CODE (CMC), NATIONAL FIRE PROTECTION ASSOCIATION (NFPA 72) AND THE CALIFORNIA ENERGY CODE (CEC).

2. THE CONTRACTOR SHALL VISIT THE JOBSITE AND VERIFY ALL EXISTING CONDITIONS PRIOR TO BIDDING THE PROJECT AND SHALL INCLUDE IN THEIR BID THE NECESSARY COSTS TO CONSTRUCT THIS PROJECT IN ACCORDANCE WITH THE ELECTRICAL DRAWINGS, SPECIFICATIONS, AND ALL APPLICABLE CODES.

3. DRAWINGS INDICATE GENERAL ARRANGEMENT OF ELECTRICAL SYSTEMS AND WORK. FOLLOW THE DRAWINGS, LAYOUT OUT WORK AND VERIFY EXACT LOCATIONS WITH ARCHITECTURAL, FLOOR PLAN AND RCP DRAWINGS. ALSO, CHECK DRAWINGS OF OTHER TRADES TO VERIFY LOCATIONS OF EQUIPMENT REQUIRING ELECTRICAL CONNECTIONS AND COORDINATE SPACE CONDITIONS WITH THEIR INSTALLATION. FINAL LOCATIONS SHALL BE ADJUSTED TO MEET FIELD CONDITIONS.

4. NOT EVERY ELECTRICAL RACEWAY, BOX, CONDUIT, ETC., FOR A COMPLETE ELECTRICAL INSTALLATION IS SHOWN ON THESE DRAWINGS. THE CONTRACTOR SHALL BE RESPONSIBLE FOR THE EASE OF INTERPRETING DRAWINGS. PROVIDE ALL ADDITIONAL ITEMS REQUIRED TO MAKE THE ELECTRICAL SYSTEMS COMPLETE AND OPERATIONAL.

5. WORK PERFORMED UNDER THIS CONTRACT SHALL CONFORM TO THESE DRAWINGS AND SHALL ALSO COMPLY WITH THE ELECTRICAL SPECIFICATIONS. IN THE EVENT THAT THERE IS A DISCREPANCY BETWEEN THE DRAWINGS AND SPECIFICATIONS, THE MORE STRINGENT OF THE REQUIREMENTS SHALL TAKE PRECEDENT.

6. ALL NEW ELECTRICAL MATERIALS AND EQUIPMENT SHALL BE UNDERWRITER'S LABORATORIES (UL) LISTED OR ELECTRICAL TESTING LABORATORIES (ETL) LISTED AND BEAR THEIR LABELS. ALL ELECTRICAL MATERIALS SHALL BE NEW AND UNUSED, AND THE SAME MANUFACTURER OF LIKE EQUIPMENT AND/OR SYSTEMS.

7. CONTRACTOR SHALL REMOVE ALL LEFTOVER CONDUIT, WIRE, SCRAP, ETC. AND LEAVE PREMISES CLEAN AND FREE OF TRASH AND DEBRIS RESULTING FROM THEIR WORK.

"DEMOLITION"

9. ALL EQUIPMENT, DEVICES, LUMINAIRES, AND RACEWAYS SHOWN AS SCREENED LINEWORK ON THESE DRAWINGS ARE EXISTING TO REMAIN, UNLESS OTHERWISE NOTED TO BE REMOVED.

10. ALL EQUIPMENT, DEVICES, LUMINAIRES, AND RACEWAYS SHOWN AS SOLID LINEWORK ON THESE DRAWINGS ARE NEW CONSTRUCTION.

11. THE EXISTING INSTALLATION SHOWN ON THESE DRAWINGS WAS DEVELOPED FROM VARIOUS SOURCES, WHICH WERE NOT ALL FIELD VERIFIED AND NOT ALL CONDITIONS ARE SHOWN. CONTRACTOR SHALL VERIFY ALL EXISTING CONDITIONS PRIOR TO CONSTRUCTION.

12. CONTRACTOR SHALL DISCONNECT AND REMOVE ALL EQUIPMENT, DEVICES, LUMINAIRES, AND RACEWAYS DENOTED TO BE DEMOLISHED ON THESE DRAWINGS. LEGALLY DISPOSE OF ALL MATERIALS THAT THE OWNER DOES NOT WANT.

13. RECONNECT EXISTING TO REMAIN DEVICES WHERE CIRCUITS HAVE BEEN INTERRUPTED BY DEMOLITION WORK TO MAINTAIN CONTINUITY. PROVIDE NEW CONNECTIONS TO ANOTHER EXISTING DEVICE OR MAIN PANEL BOARD. VERIFY CIRCUIT IDENTIFICATION AND LABELING ON EXISTING CIRCUITS BEFORE MAKING THESE CONNECTIONS.

14. WHERE EXISTING DEVICES TO BE REMOVED ARE SHOWN ON THESE DRAWINGS, THE CONTRACTOR SHALL ALSO REMOVE ALL WIRING, CONDUIT, AND BOXES SERVING THE DEVICES, UNLESS CONDUIT AND BOXES CAN BE REUSED IN NEW CONSTRUCTION.

15. WHEN A DEVICE IS REMOVED FROM AN EXISTING WALL TO REMAIN, PATCH WALL TO MATCH EXISTING OR NEW WALL FINISHES.

16. MOUNTING HEIGHTS FOR ALL NEW DEVICES SHALL BE LOCATED TO MATCH EXISTING TO REMAIN DEVICES, UNLESS OTHERWISE NOTED.

17. WHERE ADDITIONAL CIRCUITS ARE REQUIRED AND EXISTING PANELBOARDS HAVE AVAILABLE SPACE, PROVIDE NEW CIRCUIT BREAKERS IN EXISTING PANELBOARDS TO MATCH THE AIC RATINGS AND THE MANUFACTURER OF THE EXISTING BREAKERS.

18. CLEAN ALL EXISTING LUMINAIRES TO REMAIN IN AREAS INCLUDING OUT OF PHASE ORDER (E.G. 1.5, 7 OR 4.6, 10) WILL REQUIRE AN ADDITIONAL NEUTRAL CONDUCTOR, TWO (2) HOTS AND ONE (1) NEUTRAL PLUS ONE (1) HOT AND ONE (1) NEUTRAL.

"CONDUCTORS"

24. BRANCH CIRCUIT CONDUCTORS SHALL BE SIZED TO PREVENT VOLTAGE DROP EXCEEDING 3% AT THE FARTHEST OUTLET OR DEVICE. THE MAXIMUM VOLTAGE DROP ALLOWED ON COMBINED FEEDERS AND BRANCH CIRCUITS SHALL NOT EXCEED 5% TO THE FARTHEST OUTLET OR DEVICE. ALL CONDUCTORS ON THIS PROJECT SHALL BE COPPER.

25. CONDUCTORS 600VOLT OR LESS RATED SHALL UTILIZE THE AMPACITY OF THE 60-DEGREE C COLUMN OF CEC TABLE 310.16 FOR CONDUCTOR SIZES #14 AWG THROUGH #1 AWG. FOR CONDUCTOR SIZES OVER #1 AWG, UTILIZE AMPACITY FROM THE 75-DEGREE C COLUMN OF CEC TABLE 310.16.

26. MULTIWIRE BRANCH CIRCUITS SHALL ORIGINATE FROM THE SAME PANELBOARD.

27. MULTIWIRE BRANCH CIRCUITS SHALL BE PROVIDED WITH A MEANS TO SIMULTANEOUSLY DISCONNECT ALL UNGROUNDED CONDUCTORS AT THE POINT WHERE THE BRANCH CIRCUIT ORIGINATES, I.E. HANDLE TIES OR MULTIWIRE CIRCUIT BREAKERS.

28. ALL MULTIWIRE BRANCH CIRCUITS SHOWN WITH THREE (3) CONSECUTIVE PHASE CONDUCTORS (E.G., 1,3,5 OR 4,6,8), NONE SHARING THE SAME PHASE, SHALL INCLUDE A DEDICATED NEUTRAL CONDUCTOR, THREE (3) HOTS AND ONE (1) NEUTRAL. CIRCUITING OUT OF PHASE ORDER (E.G. 1,5,7 OR 4,6,10) WILL REQUIRE AN ADDITIONAL NEUTRAL CONDUCTOR, TWO (2) HOTS AND ONE (1) NEUTRAL PLUS ONE (1) HOT AND ONE (1) NEUTRAL.

29. BRANCH CIRCUIT CONDUCTORS SHALL BE INSTALLED IN CONDUIT. MC TYPE CABLE SHALL NOT BE USED FOR ANY HOMERUNS ON THIS PROJECT.

30. FEEDER CONDUCTORS SHALL BE INSTALLED IN CONDUIT, UNLESS OTHERWISE NOTED.

31. PROVIDE FEEDER CONDUIT SUPPORT IN VERTICAL RACEWAYS AS REQUIRED BY CODE, CEC 300.19.

32. WHERE MORE THAN THREE UNGROUNDED CONDUCTORS ARE ROUTED WITHIN A RACEWAY, THE CONTRACTOR SHALL APPLY THE DERATING FACTOR REQUIRED BY CODE.

"RACEWAYS"

34. MINIMUM CONDUIT TRADE SIZE FOR INTERIOR APPLICATIONS SHALL BE 0.5", UNLESS OTHERWISE NOTED.

35. CONDUIT ROUTING ON DRAWINGS IS ESSENTIALLY DIAGRAMMATIC. CONTRACTOR SHALL LAYOUT RUNS TO MEET FIELD CONDITIONS, LIGHTING DEVICES AND BOXES, AND SHALL COORDINATE INSTALLATION WITH WORK OF OTHER TRADES.

36. ALL CONDUIT AND RACEWAY PENETRATIONS THROUGH FIRE-RATED WALLS OR FLOORS SHALL BE UL LISTED ASSEMBLIES THAT PROTECTS THE RATED ASSEMBLY. SEE ARCHITECTURAL DRAWINGS FOR LOCATIONS OF ALL RATED WALLS AND FLOORS AS APPLICABLE.

37. FOR CONDUITS EMBEDDED IN CONCRETE FLOOR SLABS OR DECKS, THE MAXIMUM CONDUIT TRADE SIZE SHALL NOT EXCEED 1/2" OR 1/3" OF FLOOR THICKNESS, WHICHEVER IS SMALLER. CONDUITS SHALL BE SPACES A MINIMUM OF 6" APART, CENTER-TO-CENTER. COORDINATE LOCATION AND ROUTING WITH FLOOR WITH THE STRUCTURAL ENGINEER PRIOR TO INSTALLATION.

38. ANY BLOCKOUTS AND SLEEVING OF CONCRETE FLOORS SHALL BE PLANNED IN ADVANCED AND COORDINATED WITH THE ARCHITECT AND STRUCTURAL ENGINEER FOR THEIR APPROVALS.

39. ALL CONNECTIONS TO MECHANICAL AND PLUMBING EQUIPMENT SHALL BE MADE WITH A MINIMUM OF 3/8" SEALTIGHT FLEXIBLE METAL CONDUIT TO PREVENT SOUND AND VIBRATION TRANSMISSION TO THE STRUCTURE.

40. BUILDING EXPANSION JOINTS ARE NOT INDICATED ON THE ELECTRICAL DRAWINGS AND SHALL BE COORDINATED WITH THE ARCHITECTURAL AND STRUCTURAL DRAWINGS. INCLUDE FLEXIBLE EXPANSION RACEWAY AND WIRING METHODS AT JOINT LOCATIONS TO MEET THE DEFLECTION AND EXPANSION REQUIREMENTS OF THE BUILDING.

41. PROVIDE INSULATING BUSHINGS OR INSULATED THROAT CONNECTORS AT BOTH ENDS OF ALL CONDUIT SLEEVES.

42. DRAWINGS INDICATE JUNCTION BOXES WITH CONDUIT/CONDUCTOR HOMERUNS FOR BRANCH CIRCUITING, AS WELL AS CIRCUIT NUMBERING ADJACENT TO EQUIPMENT, DEVICES, LUMINAIRES, AND BOXES SERVED. THEY DO NOT INCLUDE CONNECTIONS BETWEEN DEVICES AND/OR LUMINAIRES. CONTRACTOR SHALL PROVIDE ALL RACEWAY AND CONDUIT/CONDUCTOR CONNECTIONS BETWEEN THE DEVICES, LUMINAIRES, AND JUNCTION BOXES AS REQUIRED AND COORDINATED WITH FIELD CONDITIONS AND OTHER TRADES.

43. MAINTAIN A MINIMUM OF 12" BETWEEN ELECTRICAL RACEWAYS AND LOW-VOLTAGE TELECOMMUNICATION SYSTEM CABLEING, INCLUDING MC CABLEING.

44. IN HARD-LID (GYPSUM BOARD) CEILING SPACES, ARRANGE CONDUIT AND CIRCUITING INSTALLATION TO AVOID AND/OR LIMIT THE USE OF JUNCTION BOXES IN OR ABOVE CEILINGS. USE OF JUNCTION BOXES ABOVE CEILINGS SHALL BE LIMITED TO LOCATIONS ACCESSIBLE FROM ACCESS PANELS.

45. ALL JUNCTION AND PULL BOXES SHALL BE SIZED PER CODE TO ACCOMMODATE NUMBER OF CONDUITS AND/OR CONDUCTORS ROUTED TO AND FROM BOXES.

46. RACEWAYS ROUTED IN EXPOSED CEILING AREAS SHALL BE RUN PARALLEL AND AT RIGHT ANGLES TO WALLS WITHIN SPACES. MC CABLE IS NOT ALLOWED IN EXPOSED CEILING SPACES.

47. PROVIDE A PULL WIRE TAPE IN ALL EMPTY CONDUIT RUNS OVER 15' IN LENGTH.

"ELECTRICAL EQUIPMENT"

48. NO PIPING, DUCTWORK, OR EQUIPMENT FOREIGN TO ELECTRICAL EQUIPMENT SHALL BE ALLOWED WITHIN THE DEDICATED SPACE ABOVE ELECTRICAL EQUIPMENT.

49. THE REQUIRED ELECTRICAL EQUIPMENT WORKING SPACE DEPTH SHALL NOT BE LESS THAN THAT INDICATED IN CEC TABLE 110.26(A)(1). THE WIDTH OF THE WORKING SPACE IN FRONT OF THE ELECTRICAL EQUIPMENT SHALL BE THE WIDTH OF THE EQUIPMENT OR 30", WHICHEVER IS GREATER. THIS REQUIREMENT ALSO APPLIES TO DISCONNECT SWITCHES.

50. FOR EQUIPMENT RATED 1200AMPS OR MORE AND OVER 6.5' WIDE, CONTAINING OVERCURRENT, SWITCHING, AND CONTROL DEVICES, THERE SHALL BE ONE ENTRANCE TO AND EGRESS FROM THE REQUIRED WORKING SPACE LOCATED AT EACH END OF THE WORKING SPACE, NOT LESS THAN 24" WIDE AND 6.5' HIGH. A SINGLE ENTRANCE TO AND EGRESS FROM THE REQUIRED WORKING SPACE SHALL BE PERMITTED WHERE EITHER UNOBSTRUCTED EGRESS OR EXTRA WORKING SPACE IS PROVIDED IN CONFORMANCE WITH THE CEC.

51. FOR EQUIPMENT RATED 800AMPS OR MORE, CONTAINING OVERCURRENT, SWITCHING, AND CONTROL DEVICES, WHERE THERE IS A PERSONNEL DOOR(S) INTENDED FOR ENTRANCE TO AND EGRESS FROM THE WORKING SPACE, WHICH IS LESS THAN 24" FROM THE NEAREST EDGE OF THE WORKING SPACE, THE DOOR(S) SHALL OPEN IN THE DIRECTION OF EGRESS AND BE EQUIPPED WITH LISTED PANIC HARDWARE.

52. PROVIDE 0.5" DEFLECTION NEOPRENE PADS FOR FLOOR AND SUSPENDED TRANSFORMERS, MASON ND/HO OR EQUAL.

53. PROVIDE 1" DEFLECTION SPRING ISOLATOR MOUNTS FOR SECONDARY SUBSTATIONS, MASON SLF OR EQUAL.

54. PROVIDE 2" DEFLECTION SPRING ISOLATOR MOUNTS FOR GENERATOR, MASON SLR OR EQUAL. UPON COMPLETION OF THE POWER SYSTEM STUDY AND REVIEW BY THE ENGINEER, THE ELECTRICAL CONTRACTOR SHALL MAKE ANY REQUIRED ADJUSTMENTS TO THE ELECTRICAL EQUIPMENT SUBMITTALS IN CONFORMANCE WITH THE STUDIES RECOMMENDATIONS AND SUBMIT FOR REVIEW BY THE ENGINEER. NO ELECTRICAL EQUIPMENT SHALL BE RELEASED FOR SHIPMENT OR INSTALLED ON-SITE PRIOR TO ENGINEER'S REVIEW OF THE POWER SYSTEM STUDY AND APPROVED ADJUSTMENTS TO ELECTRICAL EQUIPMENT SUBMITTALS.

55. CONTRACTOR SHALL PROVIDE ARC FLASH LABELS FOR ALL ELECTRICAL EQUIPMENT WITHIN THE SCOPE OF THIS PROJECT. THESE LABELS SHALL BE GENERATED BY THE CONTRACTOR FROM THE POWER SYSTEM STUDY AND SUBMITTED WITH THE POWER SYSTEM STUDY SUBMITTAL FOR ENGINEER'S REVIEW. THIS INCLUDES ALL FIELD MARKING OF AIC VALUES ON ALL BOARDS PER THE CEC.

56. PROVIDE ENGRAVED NAMEPLATES FOR ALL ELECTRICAL PANELBOARDS, SWITCHBOARDS, SWITCHGEAR, TRANSFORMERS, AND DISCONNECT SWITCHES, AS DESCRIBED IN THE SPECIFICATIONS.

57. CONTRACTOR SHALL ENSURE THAT THE ELECTRICAL EQUIPMENT PROVIDED UNDER THEIR CONTRACTOR WILL FIT WITHIN THE ELECTRICAL ROOMS AND SPACES PROVIDED IN THE BID DOCUMENTS, WHETHER PROVIDED BY THE SPECIFIED EQUIPMENT MANUFACTURER OR NOT. NO ADDITIONAL COMPENSATION WILL BE CONSIDERED IF CONTRACTOR NEEDS TO ADJUST EQUIPMENT PACKAGE TO OBTAIN REDUCED DIMENSIONS.

PROJECT GENERAL NOTES (cont.)

59. CONTRACTOR IS RESPONSIBLE FOR SUBMITTING REVISED LAYOUTS OF DISTRIBUTION EQUIPMENT IN ELECTRICAL ROOMS AND/OR SPACES. FOR APPROVAL BY ENGINEER, PROPOSED INSTALLATION DIFFERS FROM CONSTRUCTION DOCUMENTS. SUBMISSION MUST BE REVIEWED PRIOR TO RELEASE OF EQUIPMENT ORDER AND PRIOR TO INSTALLATION.

60. ALL INDOOR FLOOR OR CEILING EQUIPMENT SHALL BE MOUNTED ON A 4" HIGH CONCRETE HOUSEKEEPING PAD, WITH THE EXCEPTION OF EQUIPMENT HOUSING P&8E METER, WHICH SHALL BE LIMITED TO A 2" HIGH CONCRETE HOUSING KEEPING PAD. ALL OUTDOOR ELECTRICAL EQUIPMENT SHALL BE MOUNTED ON A 6" HIGH HOUSEKEEPING PAD. HOUSEKEEPING PADS SHALL NOT EXTEND MORE THAN 2" PAST FRONT, REAR OR SIDE FACES OF EQUIPMENT MOUNTED ON PAD.

61. OVERCURRENT PROTECTIVE DEVICES SHOWN ON DRAWINGS FOR ALL MOTOR TYPE LOADS ARE BASED ON DOCUMENTS PROVIDED PRIOR TO BID. CONTRACTOR SHALL REVIEW EQUIPMENT SUBMITTALS AND SHOP DRAWINGS FOR HVAC, PLUMBING, FIRE PROTECTION, ELEVATORS, ETC. TO CONFIRM SIZES HAVE NOT CHANGED AND MAKE ADJUSTMENTS THEY HAVE TO THE BID.

62. ALL OUTDOOR ELECTRICAL EQUIPMENT SHALL BE WEATHERPROOF (NEMA 3R RATED, MINIMUM) AND LISTED FOR EXTERIOR APPLICATIONS.

63. ALL WIRING ON PANELBOARDS, DISTRIBUTION BOARDS, SWITCHBOARDS, AND SWITCHGEAR SHALL BE DEDICATED TO CONDUCTORS TERMINATED IN THAT ENCLOSURE AND SHALL NOT BE USED AS PULL AND/OR SPICE BOXES FOR CONDUCTORS THAT TERMINATE IN OTHER ENCLOSURES.

64. ALL CIRCUIT BREAKERS SERVING THE FIRE ALARM CONTROL PANEL AND FIRE ALARM SYSTEM COMPONENTS SHALL HAVE LOCKABLE HANDLES AND SHALL BE RED IN COLOR, FOR EASE IN IDENTIFICATION.

65. PROVIDE PROTECTION FROM PHYSICAL DAMAGE FOR ALL ELECTRICAL EQUIPMENT, LUMINAIRES, WIRING DEVICES, ETC., DURING THE CONSTRUCTION OF THE PROJECT.

66. FIRE SMOKE DAMPERS (FSD) SHALL CONTAIN A MOTOR RATED ACTUATOR REQUIRING A 20AMP, 120VOLT CONNECTION WITH A LOAD OF APPROXIMATELY 75WATTS PER ACTUATOR. DEPENDING ON THE PHYSICAL SIZE OF THE FSD, THERE MAY BE A REQUIREMENT FOR MORE THAN ONE ACTUATOR. REQUIREMENTS FOR MULTIPLE CONNECTIONS, THIS SHOULD BE VERIFIED WITH HVAC CONTRACTOR. MORE THAN ONE ACTUATOR ALSO MEANS MORE THAN ONE SET OF END SWITCHES, REQUIRING MULTIPLE FIRE ALARM CONNECTIONS.

"WIRING DEVICES"

67. PROVIDE A MINIMUM OF 24" HORIZONTAL SEPARATION BETWEEN BACK-TO-BACK RECEPTACLES IN A 2-HOUR RATED WALL. REFER TO ARCHITECTURAL DRAWINGS FOR LOCATIONS OF ALL 2-HOUR RATED WALLS.

68. MOUNTING HEIGHTS OF ALL WIRING DEVICES ARE DIMENSIONED TO THE CENTER OF THE DEVICE, UNLESS OTHERWISE NOTED.

69. PROVIDE INDIVIDUAL GFCI TYPE RECEPTACLES AT EACH LOCATION SHOWN ON DRAWINGS. DO NOT APPLY THE FEED-THROUGH METHOD OF PROTECTING A NON-GFCI RECEPTACLE DOWNSTREAM OF A GFCI RECEPTACLE.

70. PROVIDE GFCI TYPE RECEPTACLES WITH WEATHER RESISTANT "WHILE-IN-USE" COVERPLATES WITHIN 20' OF ALL EXTERIOR HVAC AND PLUMBING EQUIPMENT.

71. ALL DRINKING WATER RECEPTACLES SHALL BE GFCI TYPE.

72. WHERE RECEPTACLES ARE LOCATED OUTSIDE OR IN WET/DAMP LOCATIONS, PROVIDE WEATHERPROOF WHILE-IN-USE COVERPLATES.

73. ALL WIRING DEVICES AND JUNCTION BOX COVERS SHALL HAVE TYPE-ON-TAPE LABELS INDICATING THE PANELBOARD AND CIRCUIT NUMBER(S) SERVING EACH DEVICE.

74. CONTRACTOR SHALL SIZE ALL JUNCTION AND PULL BOXES PER THE MINIMUM CODE REQUIREMENTS OF CEC ARTICLE 314, UNLESS OTHERWISE NOTED ON DRAWINGS.

75. CORE DRILLING OF CONCRETE FLOORS FOR INSTALLATION OF POKE-THROUGH DEVICES SHALL BE PLANNED IN ADVANCE AND COORDINATED WITH ARCHITECT AND STRUCTURAL ENGINEER. X-RAYS OF FLOOR MAY BE REQUIRED, IF POST-TENSION SLAB, TO ENSURE THAT CORE DRILLING DOES NOT INTERFERE WITH STRUCTURAL MEMBERS WITHIN SLAB.

"LIGHTING"

76. CONTRACTOR SHALL CONFIRM THAT ALL LUMINAIRES SPECIFIED WITH TRIMS AND FRAMES ARE COMPATIBLE WITH THE ASSOCIATED CEILING TYPES, PRIOR TO PREPARING SUBMITTAL.

77. CONTRACTOR SHALL REFER TO ARCHITECTURAL REFLECTED CEILING PLANS (RCP) FOR EXACT LOCATIONS OF ALL CEILING MOUNTED LUMINAIRES.

78. CONTRACTOR SHALL REFER TO ARCHITECTURAL ELEVATION PLANS FOR EXACT LOCATIONS OF ALL WALL MOUNTED LIGHTING FIXTURES.

79. LUMINAIRES MOUNTED IN CONTINUOUS ROWS SHALL BE THROUGH-WIRED WITHIN FIXTURE INTERNAL WIREWAY CHASE WITH CIRCUITS AND CONTROLS AS NOTED ON DRAWINGS.

80. LUMINAIRES NOT LISTED FOR THROUGH-WIRING SHALL BE WIRED WITH SEPARATE RACEWAY AND WIRING EXTERNAL TO THE LIGHTING FIXTURES.

81. ALL 0-10V LIGHTING CONTROL CABLEING, ROUTED WITHIN SAME CONDUIT AS LINE-VOLTAGE PHASE CONDUCTORS, SHALL BE 60VOLT RATED TO MATCH CONDUCTORS.

82. EMERGENCY LIGHTING SHALL BE PROVIDED THROUGHOUT THE EGRESS PATHWAY TO ILLUMINATION LEVELS OF 1 FOOT-CANDLE AVERAGE AT THE WALKING SURFACE, WITH NO POINT BEING LESS THAN 0.1 FOOT-CANDLE MINIMUM, A MAXIMUM TO MINIMUM RATIO 40 TO 1, NOT EXCEED.

83. THE SUBSCRIPT ON SWITCHES "SA" DENOTES THE LUMINAIRES CONTROLLED, WHICH IS ALSO FOUND ADJACENT TO THE CIRCUIT NUMBER AT EACH LUMINAIRE CONTROLLED BY SWITCH.

"TITLE 24 LIGHTING CONTROLS"

83. CONTRACTOR SHALL MEET THE REQUIREMENTS OF CALIFORNIA TITLE 24, OF THE CURRENTLY ADOPTED EDITION.

84. PROVIDE INDEPENDENT SWITCHING OR CONTROL DEVICE FOR EACH AREA ENCLOSED BY CEILING HEIGHT PARTITION WALLS.

85. THE CALIFORNIA ENERGY CODE SECTION 10-103 REQUIRES ACCEPTANCE TESTING ON ALL NEWLY INSTALLED LIGHTING CONTROLS, MECHANICAL SYSTEMS, ENVELOPES, AND PROCESS EQUIPMENT PRIOR TO INSTALLATION AND BEFORE PROJECT COMPLETION. AN ACCEPTANCE TEST IS A FUNCTIONAL PERFORMANCE TEST TO HELP ENSURE THAT NEWLY INSTALLED EQUIPMENT IS OPERATING AND IN COMPLIANCE WITH THE ENERGY CODE.

86. LIGHTING CONTROLS ACCEPTANCE TESTS MUST BE PERFORMED BY A CERTIFIED LIGHTING CONTROL ACCEPTANCE TEST TECHNICIAN (ATT).

87. A LISTING OF CERTIFIED ATT CAN BE FOUND AT: <https://www.energy.ca.gov/programs-and-topics/programs/acceptance-test-technician>

88. THE ACCEPTANCE TESTING PROCEDURES MUST BE REPEATED, AND DEFICIENCIES MUST BE CORRECTED BY THE BUILDER OR INSTALLING CONTRACTOR UNTIL THE CONSTRUCTION/INSTALLATION OF THE SPECIFIED SYSTEMS CONFORM AND PASS THE REQUIRED ACCEPTANCE CRITERIA. PROJECT INSPECTORS WILL COLLECT THE FORMS TO CONFIRM THAT THE REQUIRED ACCEPTANCE TESTS HAVE BEEN COMPLETED.

89. MULTI-LEVEL LIGHTING CONTROL IS REQUIRED FOR ALL GENERAL LIGHTING IN ENCLOSED SPACES, 100 SQUARE FEET OR LARGER, WITH A CONNECTED LOAD EXCEEDING 0.5W/SQFT. PROVIDE CONTROLS AS FOLLOWS:

- LOCAL MANUAL DIMMING VIA DIMMING SWITCH.
- CENTRAL MANUAL DIMMING VIA DIMMING MODULE AT THE LIGHTING CONTROL PANEL AND LOCAL DIMMING SWITCH.
- AUTOMATIC DAYLIGHT HARVESTING IN BOTH PRIMARY AND SECONDARY DAYLIGHT ZONES.

"FEEDER TAGS"

90. FEEDER TAGS SHALL BE PROVIDED FOR ALL FEEDERS. FEEDER TAGS SHALL BE PROVIDED FOR ALL FEEDERS. FEEDER TAGS SHALL BE PROVIDED FOR ALL FEEDERS.

SYMBOLS LIST

SOME OF THESE SYMBOLS SHOWN MAY NOT BE USED ON THIS PROJECT

WIRING DEVICES

JUNCTION BOX, WALL MOUNTED, +18" UON.

JUNCTION BOX, MOUNTED IN FLUSH FLOOR BOX.

JUNCTION BOX, MOUNTED IN FLUSH IN CEILING.

JUNCTION BOX, SURFACE OR PENDANT MOUNTED TO BOTTOM OF STRUCTURE IN ACCESSIBLE CEILING SPACE OR EXPOSED IN OPEN CEILING AREAS.

JUNCTION BOX, MOUNTED ON CONDUIT STANCHION FLOOR PENETRATION, +12" UON.

SINGLE-PLEX CONVENIENCE RECEPTACLE DEVICE, WALL MOUNTED, +18" UON.

DUPLEX CONVENIENCE RECEPTACLE DEVICE, WALL MOUNTED, +18" UON. LETTERING ADJACENT TO THE DEVICE ON THE PLANS INDICATE THE FOLLOWING FOR THOSE RECEPTACLES:

- A: ARC FAULT CURRENT INTERRUPTER (AFCI)
- G: GROUND FAULT CURRENT INTERRUPTER (GFCI)
- IG: ISOLATED GROUND
- TR: TAMPER RESISTANT
- U: INTEGRAL USB PORTS
- WP: WEATHER-RESISTANT, GROUND FAULT CURRENT INTERRUPTER (GFCI) WITH WEATHERPROOF "IN USE" COVER

DOUBLE DUPLEX CONVENIENCE RECEPTACLE DEVICE, WALL MOUNTED, +18" UON.

CONVENIENCE RECEPTACLE DEVICE, WALL MOUNTED OVER CONDUIT, 6" ABOVE BACK SPLASH UON, BUT NO HIGHER THAN ADA REQUIREMENTS.

CONVENIENCE RECEPTACLE DEVICE, SPLIT-WIRED, WALL MOUNTED, +18" UON.

CONVENIENCE RECEPTACLE DEVICE, ON BACK-UP POWER SYSTEM, WALL MOUNTED, +18" UON.

CONVENIENCE RECEPTACLE DEVICE, CONTROLLED PER T24, WALL MOUNTED, +18" UON.

DUPLEX CONVENIENCE RECEPTACLE DEVICE, HORIZONTALLY WALL MOUNTED, +18" UON.

DUPLEX CONVENIENCE RECEPTACLE DEVICE, MOUNTED IN FLUSH FLOOR BOX.

DOUBLE DUPLEX CONVENIENCE RECEPTACLE DEVICE, MOUNTED IN FLUSH FLOOR BOX.

COMBINATION POWER/TELECOMMUNICATION DEVICE, MOUNTED IN FLUSH FLOOR BOX.

DUPLEX CONVENIENCE RECEPTACLE DEVICE, MOUNTED IN FIRE-RATED POKE-THRU FLOOR FITTING.

DOUBLE DUPLEX CONVENIENCE RECEPTACLE DEVICE, MOUNTED IN FIRE-RATED POKE-THRU FLOOR FITTING.

COMBINATION POWER/TELECOMMUNICATION DEVICE, MOUNTED IN FIRE-RATED POKE-THRU FLOOR FITTING. TYPE AS NOTED ON PLANS OR IN SPECIFICATIONS.

DUPLEX CONVENIENCE RECEPTACLE DEVICE, MOUNTED FLUSH IN CEILING.

DOUBLE DUPLEX CONVENIENCE RECEPTACLE DEVICE, MOUNTED FLUSH IN CEILING.

DUPLEX CONVENIENCE RECEPTACLE DEVICE, MOUNTED ON CONDUIT STANCHION FLOOR PENETRATION, +12" UON.

DUPLEX CONVENIENCE RECEPTACLE DEVICE, CORD OR REEL HUNG FROM STRUCTURE ABOVE. TYPE AS NOTED ON PLANS.

CONVENTIONS

NUMBERED NOTE, APPLIES TO ALL DRAWINGS.

NUMBERED SHEET NOTE, APPLIES TO DRAWING CONTAINING NOTES ONLY.

OVERCURRENT PROTECTIVE DEVICE NUMBER IDENTIFICATION TAG. REFERS TO LOCATION OF PROTECTIVE OR CONTROL DEVICE WITHIN SWITCHBOARDS, DISTRIBUTION BOARDS, MOTOR CONTROL DEVICES.

EQUIPMENT IDENTIFICATION TAG. ITEM FURNISHED AND INSTALLED UNDER ANOTHER DIVISION AND WIRED UNDER THIS DIVISION.

FEEDER TAG. REFER TO FEEDER SCHEDULE.

DETAIL REFERENCE:

DETAIL DESIGNATION

SHEET NUMBER

FIXTURE/DEVICE IDENTIFICATION TAG:

FIXTURE/DEVICE TYPE

QUANTITY

UNDERGROUND CONDUIT DESIGNATION:

CONDUIT SIZE IN INCHES

CONDUIT SYSTEM DESIGNATION

P: PRIMARY POWER

S: SECONDARY POWER

T: TELECOMMUNICATIONS

QUANTITY OF CONDUITS

SWITCHBOARDS, DISTRIBUTION BOARDS, AND PANELBOARDS:

BOARD DESIGNATION

FLOOR NUMBER

VOLTAGE CLASSIFICATION

PS: PRIMARY SUBSTATION SS: SECONDARY SUBSTATION

MS: MAIN SWITCHBOARD LD: 277/480 DIST. BOARD

H: 277/480 PANELBOARD LD: 120/208 DIST. BOARD

L: 120/208 PANELBOARD

MOTOR CONTROL CENTERS:

MCC DESIGNATION

FLOOR NUMBER

MOTOR CONTROL CENTER

TRANSFORMERS:

TRANSFORMER DESIGNATION

FLOOR NUMBER

TRANSFORMER

POWER SOURCE

N: NORMAL

- E: EMERGENCY OR ESSENTIAL
- C: CRITICAL
- S: LIFE SAFETY OR LEGALLY REQUIRED
- U: UPS
- STANDBY
- O: OPTIONAL STANDBY

SIGNAL SYSTEM TERMINALS:

TERMINAL DESIGNATION

FLOOR NUMBER

TERMINAL TYPE

TC: TERMINAL CABINET

TE: TERMINAL ASSIGNATION

D: DATA

FA: FIRE ALARM

S: SECURITY

T: TELEPHONE

TV: TELEVISION

BUILDING NUMBER (WHEN APPLICABLE)

LINE VOLTAGE LIGHTING CONTROL

S SINGLE-POLE, SINGLE-THROW SWITCH, WALL MOUNTED, +42" UON. LETTERING ADJACENT TO THE DEVICE ON THE PLANS INDICATE THE FOLLOWING FOR THE DEVICES:

- 3: THREE-WAY
- 4: FOUR-WAY
- K: KEY-OPERATED
- P: WITH PILOT LIGHT
- TC: TIMER CONTROLLED
- EP: EXPLOSION PROOF
- OC: OCCUPANCY SENSOR
- WP: WEATHERPROOF COVER
- H: AUTOMATIC HUMIDITY CONTROL
- M: DUAL-LEVEL OCCUPANCY SENSOR
- M1: SINGLE-LEVEL OCCUPANCY SENSOR
- DM: COMBO OCCUPANCY SENSOR AND DIMMER

S^D WALLBOX DIMMER SWITCH, +42" UON. SIZED PER CONNECTED LOAD ON PLANS AND FURNISHED FOR LAMP SOURCE SERVED. PROVIDED FOR DERATING WHEN INSTALLED GANGED LOCATIONS.

OS OCCUPANCY SENSOR FOR AREA COVERAGE, CEILING MOUNTED.

PC PHOTOELECTRIC CELL SENSOR, CEILING MOUNTED.

EXISTING TO REMAIN

NEW CONSTRUCTION

EXISTING TO BE REMOVED (R) OR RELOCATED (RR)

FUTURE CONSTRUCTION

SYMBOLS LIST

SOME OF THESE SYMBOLS SHOWN MAY NOT BE USED ON THIS PROJECT

LIGHTING

LUMINAIRE, RECESSED IN CEILING.

LUMINAIRE, SURFACE MOUNTED.

SUSPENDED LINEAR LUMINAIRE. SUSPENSION POINTS ARE GRAPHIC ONLY AND DO NOT REPRESENT ACTUAL LOCATION OR QUANTITY.

LUMINAIRE, WALL MOUNTED.

STRIP LUMINAIRE, SURFACE OR PENDANT MOUNTED.

STRIP LUMINAIRE, SURFACE MOUNTED IN ARCHITECTURAL CEILING COVE.

STRIP LUMINAIRE, SURFACE MOUNTED VERTICALLY ON WALL OR IN COVE.

ROUND DOWNLIGHT LUMINAIRE, RECESSED IN CEILING.

SQUARE DOWNLIGHT LUMINAIRE, RECESSED IN CEILING.

DOWNLIGHT/INDUSTRIAL LUMINAIRE, SURFACE OR PENDANT MOUNTED.

DIRECTIONAL LUMINAIRE, RECESSED IN CEILING.

DIRECTIONAL LUMINAIRE, SURFACE OR PENDANT MOUNTED.

LINEAR, MULTI-HEAD, ADJUSTABLE ACCENT LUMINAIRES, RECESSED IN CEILING.

LINEAR WALL WASH LUMINAIRE, RECESSED IN CEILING.

LINEAR WALL WASH LUMINAIRE, SURFACE OR PENDANT MOUNTED.

SCENCE LUMINAIRE, WALL MOUNTED.

LED TAPE STRIP TYPE LUMINAIRE, MOUNTED LOOSE OR IN CHANNEL.

DECORATIVE LUMINAIRE, PENDANT MOUNTED.

LINEAR TRACK SYSTEM WITH PLUG-IN ADJUSTABLE LUMINAIRE HEADS. TRACK SHALL BE EITHER RECESSED, SURFACE OR PENDANT MOUNTED TO CEILING AS NOTED IN LUMINAIRE SCHEDULE. 'X' NEXT TO JUNCTION BOX REPRESENTS INTEGRAL CURRENT LIMITER TRIP RATING.

EXIT SIGN LUMINAIRE, CEILING OR WALL MOUNTED WITH DIRECTIONAL ARROWS AS NOTED ON PLANS. WORD 'EXIT' TO BE LOCATED IN SHADED FACE(S).

COMBO EXIT SIGN AND EGRESS LUMINAIRE, CEILING OR WALL MOUNTED WITH ARROWS AS NOTED ON PLANS OR IN LUMINAIRE SCHEDULE.

EMERGENCY SELF-POWERED BATTERY PACK WITH LUMINAIRE HEADS AS NOTED ON PLANS OR IN LUMINAIRE SCHEDULE.

SHADING OF ANY LUMINAIRE INDICATES EMERGENCY/EGRESS LIGHTING.

HALF SHADING OF ANY LUMINAIRE INDICATES CRITICAL/STANDBY LIGHTING.

SINGLE-HEAD AREA LUMINAIRE WITH BRACKET ARM AND POLE, MOUNTED TO CONCRETE BASE.

TWO-HEAD AREA LUMINAIRE WITH BRACKET ARMS AND POLE, MOUNTED TO CONCRETE BASE.

SINGLE-HEAD AREA POST-TOP LUMINAIRE WITH POLE, MOUNTED TO CONCRETE BASE.

AREA LUMINAIRE, SURFACE OR RECESSED MOUNTED TO WALL.

LUMINAIRE BOLLARD, MOUNTED TO CONCRETE BASE.

GROUNDWELD LUMINAIRE MOUNTED FLUSH IN FINISHED GRADE.

FLOODLIGHT LUMINAIRE, STANCHION MOUNTED ABOVE GRADE.

LINEAR SIGN LIGHT LUMINAIRE, STANCHION MOUNTED ABOVE GRADE.

STEPLIGHT LUMINAIRE, WALL MOUNTED.

MULTIPLE LUMINAIRES MOUNTED ON COMMON POLE.

F.A.A OBSTRUCTION LUMINAIRE.

POWER DISTRIBUTION

SWITCHGEAR, SWITCHBOARD, DISTRIBUTION BOARD, SUBSTATION OR MOTOR CONTROL CENTER, FLOOR MOUNTED ON CONCRETE HOUSEKEEPING PAD WHERE INDICATED ON DRAWINGS. DOUBLE LINE INDICATES FRONT FACE OF GEAR.

DISTRIBUTION BOARD, SURFACE MOUNTED ON WALL.

PANELBOARD, 277/480V, SURFACE MOUNTED ON WALL.

PANELBOARD, 277/480V, FLUSH MOUNTED IN WALL.

PANELBOARD, 120/208V, SURFACE MOUNTED ON WALL.

PANELBOARD, 120/208V, FLUSH MOUNTED IN WALL.

DRY-TYPE STEP-DOWN TRANSFORMER, FLOOR MOUNTED 480-120/208V 3Ø, UON. DOUBLE LINE INDICATES FRONT FACE OF TRANSFORMER.

ELECTRIC MOTOR, NEC. MAKE POWER CONNECTIONS ONLY AS NOTED ON PLANS.

EXHAUST FAN MOTOR, SINGLE PHASE, NEC. MAKE POWER CONNECTIONS TO INCLUDE JUNCTION BOX MOUNTED, FRACTIONAL HORSEPOWER MANUAL STARTER WITH INTEGRAL DISCONNECT ADJACENT TO FAN WITH 2 #12 CONDUCTORS PLUS GROUND IN 1/2" FLEXIBLE CONDUIT BETWEEN STARTER AND MOTOR.

INDOOR FAN POWERED VAV BOX MOTOR, SINGLE PHASE, NEC. MAKE POWER CONNECTIONS TO INCLUDE JUNCTION BOX MOUNTED, FRACTIONAL HORSEPOWER MANUAL MOTOR STARTER WITH INTEGRAL DISCONNECT ADJACENT TO VAV BOX WITH 2 #12 CONDUCTORS PLUS GROUND IN 1/2" FLEXIBLE CONDUIT BETWEEN STARTER AND MOTOR.

MOTOR OPERATED FIRE/SMOKE DAMPER (FSD). NEC. SYMBOL DENOTES INTERFACE FOR POWER CONNECTIONS WITH LOCAL DISCONNECT MEANS. ADJACENT NUMBER INDICATES QUANTITY OF ACTUATORS PER FSD, EACH REQUIRING A POWER CONNECTION, IF MORE THAN 1. FOR FIRE ALARM REQUIREMENTS AT FSD, REFER TO FIRE ALARM SYMBOLS.

COMBINATION EXHAUST FAN AND DOWNLIGHT, CEILING MOUNTED. FAN AND LIGHT SHALL BE CONTROLLED SEPARATELY.

SAFETY DISCONNECT SWITCH, 3 POLE, UON. ADJACENT NUMBER INDICATES FUSE SIZE WHEN APPLICABLE. LABELING CONVENTION AS FOLLOWS:

- A: 30A, NON-FUSED
- B: 60A, NON-FUSED
- C: 100A, NON-FUSED
- D: 200A, NON-FUSED
- E: 400A, NON-FUSED
- F: 600A, NON-FUSED
- G: 800A, NON-FUSED
- AF: 30A, FUSED
- BF: 60A, FUSED
- CF: 100A, FUSED
- DF: 200A, FUSED
- EF: 400A, FUSED
- FF: 600A, FUSED
- GF: 800A, FUSED

LINESTYLES

EXISTING TO REMAIN

NEW CONSTRUCTION

EXISTING TO BE REMOVED (R) OR RELOCATED (RR)

FUTURE CONSTRUCTION

SYMBOLS LIST

SOME OF THESE SYMBOLS SHOWN MAY NOT BE USED ON THIS PROJECT

FIRE ALARM

SMOKE DETECTOR INITIATING DEVICE, CEILING MOUNTED IN FLUSH OR SURFACE JUNCTION BOX. "C" DENOTES MULTI-CRITERIA CARBON MONOXIDE AND SMOKE DETECTOR.

SMOKE DETECTOR INITIATING DEVICE, WALL MOUNTED IN FLUSH JUNCTION BOX, MAXIMUM 6" BELOW CEILING.

SMOKE DETECTOR INITIATING DEVICE, MOUNTED TO STRUCTURE ABOVE SUSPENDED CEILING IN SURFACE JUNCTION BOX OR SUSPENDED IN JUNCTION BOX.

SMOKE DETECTOR INITIATING DEVICE, DUCT-MOUNTED TYPE WITH SAMPLING TUBE.

SMOKE DETECTOR INITIATING DEVICE, IN-DUCT MOUNTED TYPE.

PROJECTED BEAM SMOKE DETECTOR INITIATING DEVICES TO INCLUDE TRANSMITTER, RECEIVER AND REMOTE INDICATOR STATION, WALL MOUNTED IN FLUSH JUNCTION BOX BELOW BEAM DETECTOR AT +42" AFF. BEAM DETECTORS ARE EITHER CEILING OR WALL MOUNTED TO 6" BELOW CEILING.

HEAT DETECTOR INITIATING DEVICE, CEILING MOUNTED IN FLUSH OR SURFACE JUNCTION BOX.

HEAT DETECTOR INITIATING DEVICE, WALL MOUNTED IN FLUSH JUNCTION BOX, MAXIMUM 6" BELOW CEILING.

HAND DETECTOR INITIATING DEVICE, MOUNTED TO STRUCTURE ABOVE SUSPENDED CEILING IN SURFACE JUNCTION BOX.

MANUAL PULL STATION INITIATING DEVICE, WALL MOUNTED AT +48" UON.

SPRINKLER SYSTEM WATER FLOW SWITCH, NEC. SYMBOL DENOTES INTERFACE FOR MONITORING CONNECTION FROM FIRE ALARM SYSTEM.

SPRINKLER SYSTEM TAMPER SWITCH, NEC. SYMBOL DENOTES INTERFACE FOR MONITORING CONNECTION FROM FIRE ALARM SYSTEM.

SPRINKLER SYSTEM POST INDICATING VALVE (PIV). NEC. SYMBOL DENOTES INTERFACE FOR MONITORING CONNECTION FROM FIRE ALARM SYSTEM. INCLUDE A REMOTE MOUNTED ADDRESSABLE MONITORING MODULE AT PIV.

REMOTE MOUNTED SINGLE INPUT, ADDRESSABLE, MONITORING MODULE FOR INITIATING CIRCUIT CONNECTION.

REMOTE MOUNTED DUAL INPUT, ADDRESSABLE, MONITORING MODULE FOR INITIATING CIRCUIT CONNECTION.

REMOTE MOUNTED PROGRAMMABLE CONTROL RELAY MODULE FOR ADDRESSABLE CONTROL.

DIFFERENTIAL PRESSURE SWITCH, NEC. SYMBOLS DENOTES INTERFACE FOR MONITORING CONNECTION FROM FIRE ALARM SYSTEM TO ANNUNCIATE FAN OPERATION. INCLUDE A REMOTE MOUNTED ADDRESSABLE MONITORING MODULE AT EACH LOCATION.

END-OF LINE RESISTOR.

CURRENT TRANSFORMER FOR MONITORING AVAILABLE POWER.

FIREMANS REMOTE ANNUNCIATOR PANEL FRAP, FLUSH WALL MOUNTED, +42" UON.

MAGNETIC TYPE DOOR HOLD OPEN/RELEASE DEVICE, WALL MOUNTED, NEC. SYMBOL DENOTES INTERFACE FOR POWER AND CONTROL CONNECTIONS FROM FIRE ALARM SYSTEM.

DOOR HOLD OPEN/RELEASE DEVICE INTEGRATED IN DOOR HARDWARE CLOSURE EQUIPMENT, NEC. SYMBOL DENOTES INTERFACE FOR POWER AND CONTROL CONNECTIONS FROM FIRE ALARM SYSTEM.

AUDIBLE NOTIFICATION APPLIANCE, WALL MOUNTED, 6" BELOW CEILING OR +80" AFF, WHICHEVER IS LOWER.

VISIBLE NOTIFICATION APPLIANCE, WALL MOUNTED, 6" BELOW CEILING OR +80" AFF, WHICHEVER IS LOWER. NUMBER ASSOCIATED WITH 'vd' REPRESENTS CANDELA RATING OF STROBE.

AUDIBLE/VISIBLE NOTIFICATION APPLIANCE, WALL MOUNTED, 6" BELOW CEILING OR +80" AFF, WHICHEVER IS LOWER. NUMBER ASSOCIATED WITH 'vd' REPRESENTS CANDELA RATING OF STROBE.

AUDIBLE NOTIFICATION APPLIANCE, CEILING MOUNTED IN FLUSH BACK BOX.

VISIBLE NOTIFICATION APPLIANCE, CEILING MOUNTED IN FLUSH BACK BOX. NUMBER ASSOCIATED WITH 'vd' REPRESENTS CANDELA RATING OF STROBE.

AUDIBLE/VISIBLE NOTIFICATION APPLIANCE, CEILING MOUNTED IN FLUSH BACK BOX. NUMBER ASSOCIATED WITH 'vd' REPRESENTS CANDELA RATING OF STROBE.

MOTOR OPERATED FIRE/SMOKE DAMPER (FSD). NEC. SYMBOL DENOTES FIRE ALARM INTERFACE WITH PROGRAMMABLE CONTROL RELAY FOR FSD AND CONTROL AND DUAL INPUT ADDRESSABLE MONITORING MODULE FOR POSITION MONITORING VIA END SWITCHES.

THERMISTOR SENSOR DEVICE IN FSAE LOBBIES FOR TEMPERATURE MONITORING, WALL MOUNTED 6" BELOW CEILING.

SMOKE ALARM FOR RESIDENTIAL DWELLING UNITS, NON-ADDRESSABLE, 120V DEVICE WITH BATTERY BACK-UP, CEILING MOUNTED IN FLUSH OR SURFACE JUNCTION BOX.

SMOKE ALARM FOR RESIDENTIAL DWELLING UNITS, NON-ADDRESSABLE, 120V DEVICE WITH BATTERY BACK-UP, WALL MOUNTED MAXIMUM 6" BELOW CEILING IN FLUSH JUNCTION BOX.

COMBINATION SMOKE AND CARBON MONOXIDE ALARM FOR RESIDENTIAL DWELLING UNITS, NON-ADDRESSABLE, 120V DEVICE WITH BATTERY BACK-UP, CEILING MOUNTED IN FLUSH OR SURFACE JUNCTION BOX.

COMBINATION SMOKE AND CARBON MONOXIDE ALARM FOR RESIDENTIAL DWELLING UNITS, NON-ADDRESSABLE, 120V DEVICE WITH BATTERY BACK-UP, WALL MOUNTED MAXIMUM 6" BELOW CEILING IN FLUSH JUNCTION BOX.

REMOTE 2-WAY COMMUNICATION STATION, WALL MOUNTED, +42" AFF.

2-WAY COMMUNICATION BASE STATION, WALL MOUNTED, +42" AFF.

CLOCK, PA, INTERCOM

INDICATING CLOCK WITH CLOCK OUTLET, WALL MOUNTED, 12" BELOW CEILING OR +96" AFF, WHICHEVER IS LOWER.

COMBINATION LOUSPEAKER/INDICATING CLOCK WITH CLOCK OUTLET, WALL MOUNTED IN COMBINATION BACK BOX, 12" BELOW CEILING OR +96" AFF, WHICHEVER IS LOWER.

PA LOUSPEAKER, WALL MOUNTED, 12" BELOW CEILING OR +96" AFF, WHICHEVER IS LOWER.

PA LOUSPEAKER, CEILING MOUNTED IN FLUSH BACK BOX, 25V, 70V, 100V OR IP AS INDICATED ON DRAWINGS AND SPECS.

INTERCOM STATION, WALL MOUNTED, +42" UON. 'M' DENOTES MASTER STATION.

INTERCOM STATION, MOUNTED ON DESK. 'M' DENOTES MASTER STATION.

ELECTRICAL SHEET INDEX

SHEET NO.	GENERAL NOTES AND SYMBOLS	SHEET NAME
E.0		
E.1	POWER AND LIGHTING PLAN	
E.2	DETAILS	

The Engineering Enterprise

CONSULTING ENGINEERS

ALAMEDA | ALBUQUERQUE | CHICO | IRVINE
LOS ANGELES | MESA | PHOENIX
SAN ANTONIO | SAN DIEGO
SANTA BARBARA | SAN JOSE

<https://www.engeer.com>

PROFESSIONAL
REGISTERED
Exp. 02/21/2026

CRISTINA MARTIN
REGISTERED PROFESSIONAL
STATE OF CALIFORNIA

REVISIONS

#	DESCRIPTION	DATE

DESIGNER-Designer

SCALE: NTS

DATE: 2024.01.20

TITLE:

GENERAL NOTES AND SYMBOLS

DRAWING NO.

E0.0

MCCLATCHY HS TRAINING ROOMS

1305 Marina Village Parkway


0 1/4" = 1'-0"

IF THIS SHEET IS NOT 30"x42", IT IS A REDUCED PRINT. SCALE ACCORDINGLY.

5/2/2020 10:19:58 AM


Autodesk Docs:020030-SD-US01 HS Training Rooms-SD-US01 McClatchy HS Training Rooms_24.rvt

LUMINAIRE SCHEDULE									
LUMINAIRE SCHEDULE NOTES: REFER TO SPECIFICATION "265000 LIGHTING" FOR DETAILS ON TIER REQUIREMENTS. IN ABSENCE OF SPECIFICATION SECTION, REFER TO THE FOLLOWING TIER DEFINITIONS:									
TIER 1 (LEGACY CRI 90): FOR APPLICATIONS WHERE COLOR FIDELITY IS CRITICAL, SUCH AS MUSEUMS, GALLERIES, HIGH-END RESIDENTIAL, ETC. R9 VALUE: MINIMUM 80. TM30 VALUES: Rf>85, 95-Rg<105.									
TIER 2 (LEGACY CRI 80): FOR APPLICATIONS WHERE COLOR FIDELITY IS IMPORTANT, SUCH AS OFFICES, SCHOOLS, GENERAL INTERIOR AREAS, ETC. R9 VALUE: MINIMUM 30. TM30 VALUES: Rf>75, 92-Rg<110.									
TIER 3 (LEGACY CRI 70): FOR APPLICATIONS WHERE COLOR FIDELITY IS NOT CRITICAL, SUCH AS EXTERIOR PARKING AND AREA LIGHTING, WAREHOUSES, ETC. R9 VALUE: MINIMUM 20. TM30 VALUES: Rf>70, 88-Rg<120.									
TYPE	IMAGE	MANUFACTURER CATALOG NUMBER	DESCRIPTION	LIGHT SOURCE	TIER	DRIVER, TRANSFORMER	WATTAGE	VOLTAGE	DETAIL
F1		PRUDENTIAL "HALF SNAP" SERIES HSS-LED35-SO-4-SAL-TMW-UNV-SUR-X3-DM1 O OR APPROVED EQUAL	NOMINAL 4' LONG SURFACE MOUNTED COMPACT LINEAR LED FIXTURE, WITH STEEL HOUSING WITH WHITE POWDER COAT FINISH, AND DIFFUSE SNAP-ON LENS. INSTALL IN CONTINUOUS ROW WHERE INDICATED ON THE PLANS.	LED 10W/1FT ~1300LUMENS/F 3500K 80+ CRI MIN 100,000HR L90	TIER 2	0-10V DIM	0 W / FT 10 W / FT	277 V 120 V	1/E2.0

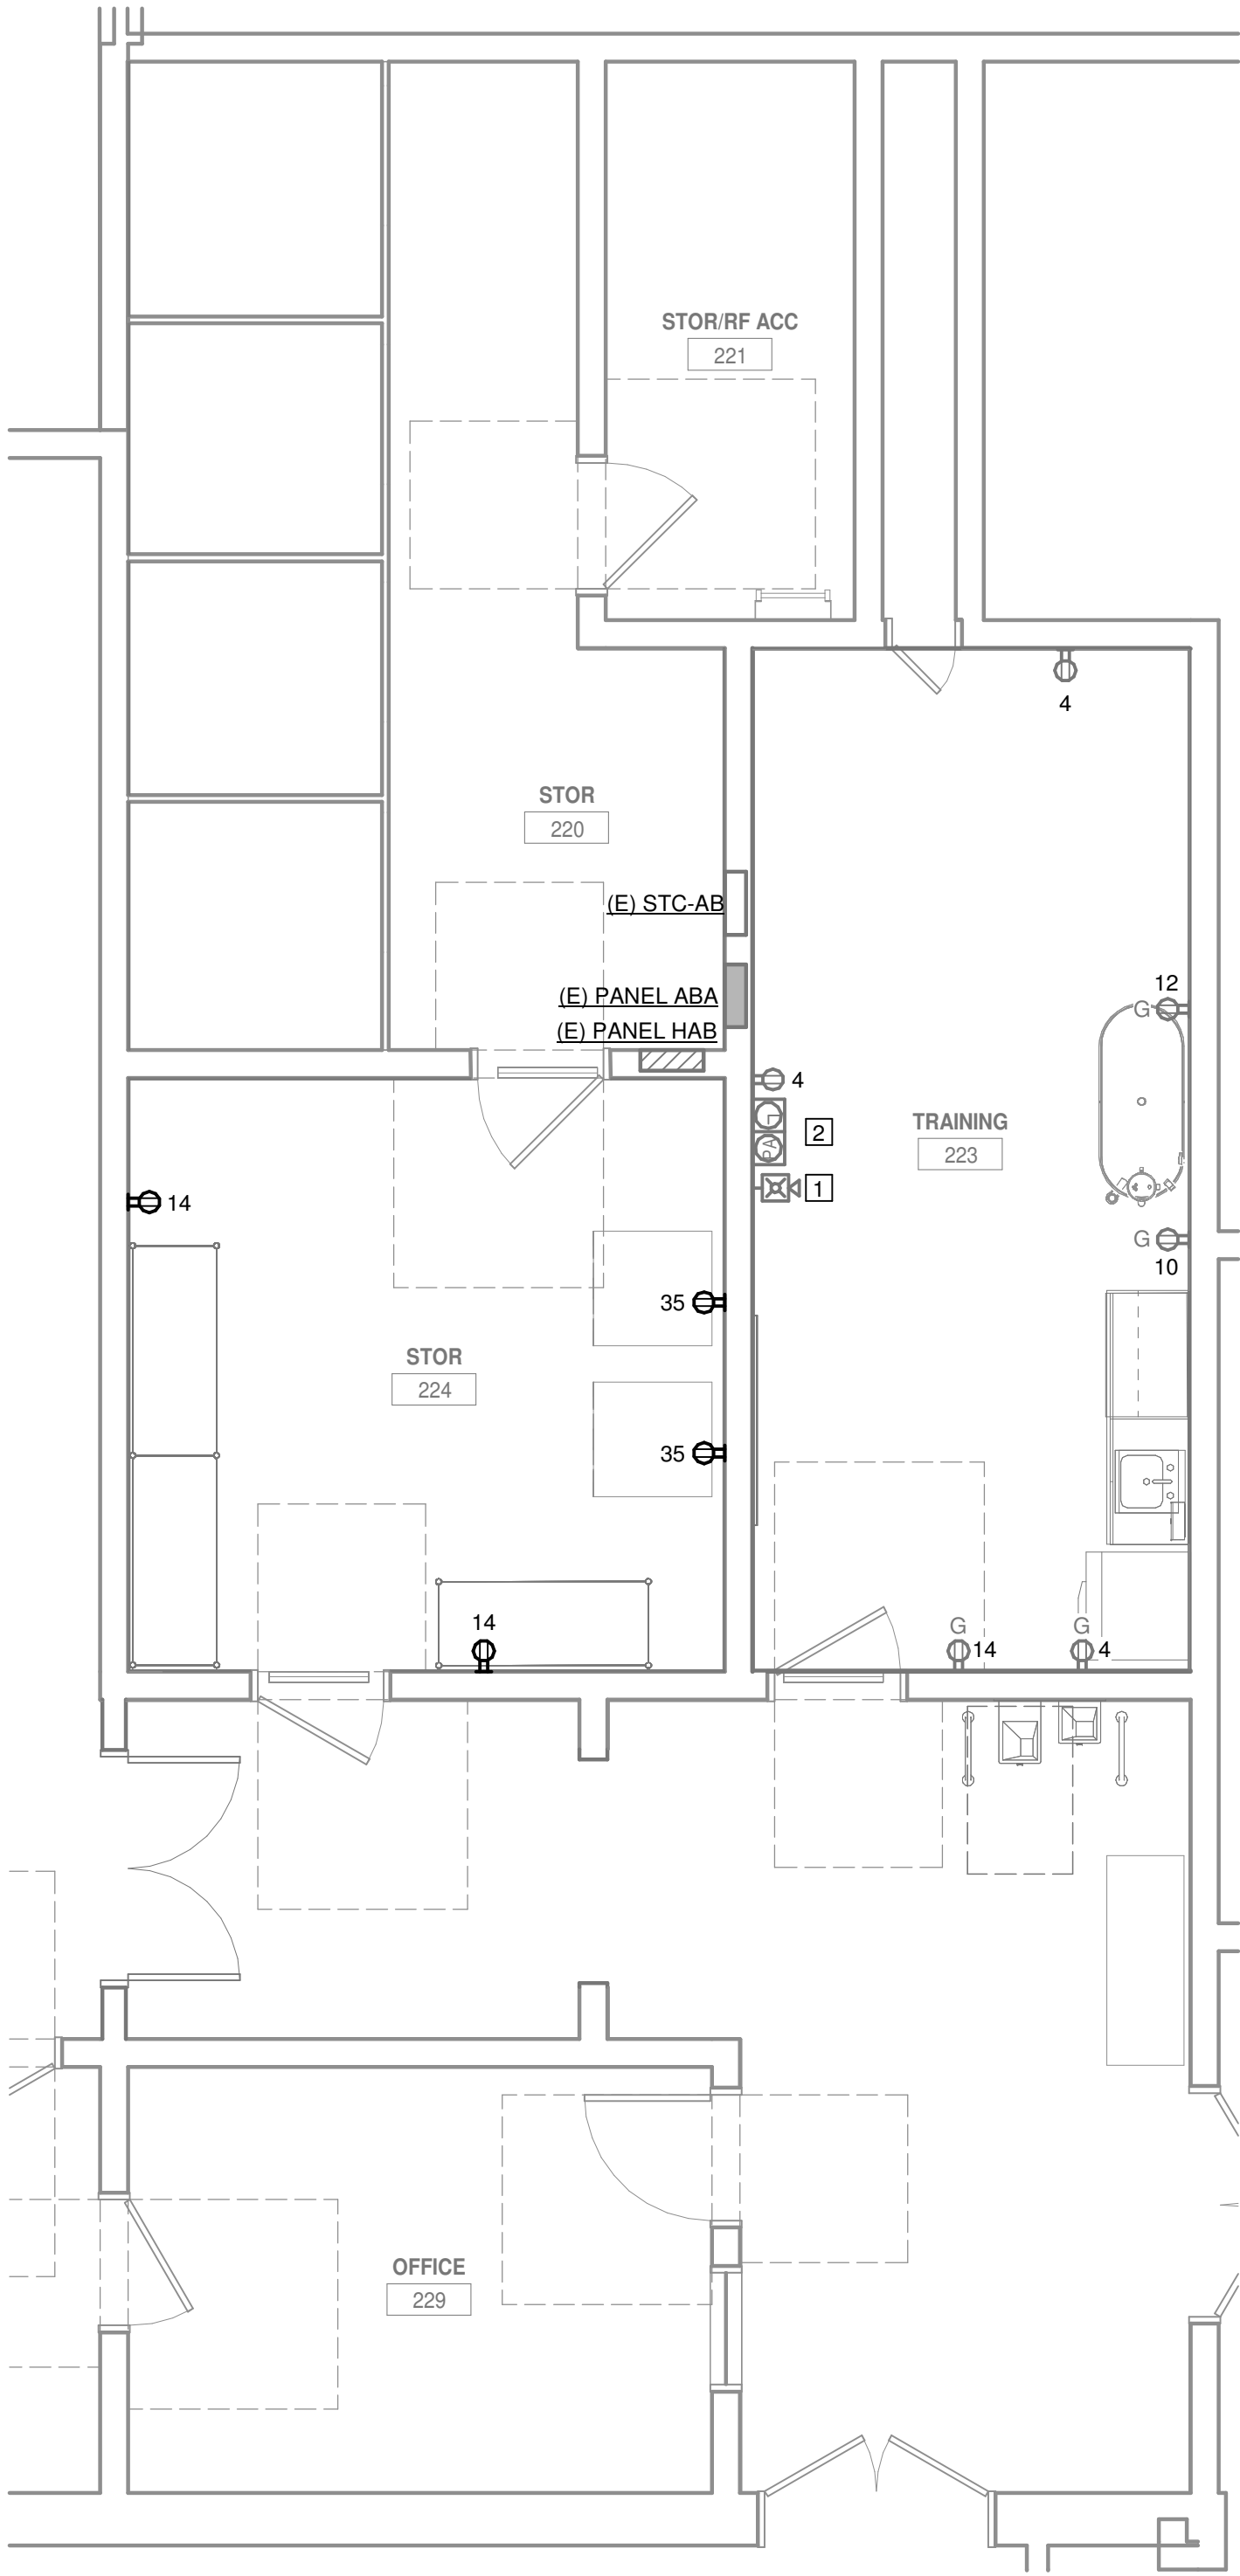

1 POWER PLAN
SCALE: 1/4" = 1'-0"

Branch Panel: (E) PANEL ABA												
Location: TRAINING 223												
Mounting: SURFACE												
		Served From			Phases 3		A.I.C. Rating:		Bus Rating: 100 A			
		Volts: 120/208			Wires 4		Main Type:		Main Rating: NA			
LC	Load Served	Amp	P	#	A (kVA)	B (kVA)	C (kVA)	#	P	Load Served	LC	
--	(E) EMERGENCY LIGHTS	20 A	1	1	0.00	0.00		2	1	20 A (E) EMERGENCY LIGHTS / GYM	--	
--	(E) REF - 6, 7	20 A	1	3		0.00	0.54		4	1	20 A (E) TRAINING RM REC.	R
--	(E) RECEPTS / SCORE	20 A	1	5			0.00	0.00	6	1	20 A (E) REF-1	--
--	(E) RECEPTS	20 A	1	7	0.00	0.00		8	1	20 A (E) REF-3	--	
--	(E) RECEPTS / SHOTS	20 A	1	9		0.00	0.18		10	1	20 A (E) HYDRO BATH	Nc
--	SPARE	20 A	1	11			0.00	0.18	12	1	20 A (E) HYDRO BATH	Nc
--	SPARE	20 A	1	13	0.00	0.54			14	1	20 A (E) TRAINING / STORAGE REC.	R
--	(E) EMERGENCY LIGHTING	20 A	1	15		0.00	0.00		16	1	20 A REF-2	--
--	(E) FIRE ALARM	20 A	1	17			0.00	0.00	18	1	20 A (E) HAND DRYER G5	--
--	(E) VEP-1	20 A	1	19	0.00	0.00			20	1	20 A (E) HAND DRYER B7	--
--	(E) ASSISTIVE LISTENING	20 A	1	21		0.00	0.00		22	1	20 A (E) HAND DRYER B5	--
--	(E) WRESTLING LTS	20 A	1	23			0.00	0.00	24	1	20 A (E) HAND DRYER B6	--
--	(E) PANEL ABB	20 A	1	25	0.00	0.00			26	1	20 A (E) HAND DRYER COACH	--
--	(E) PANEL ABB	20 A	1	27					28			--
--	(E) PANEL ABB	20 A	1	29			0.00	0.00	30			--
--	(E) GYM CONTROLLER	30 A	1	31	0.00	0.00			32	1	20 A (E) BLEACHERS	--
--	(E) GYM CONTROLLER	30 A	1	33		0.00	0.00		34	1	20 A (E) BLEACHERS	--
R	STORAGE REF	20 A	1	35			0.36	0.00	36	1	20 A (E) BLEACHERS	--
--		0 A	1	37	0.00				38			--
--		0 A	1	39		0.00			40			--
--		0 A	1	41			0.00		42			--
Connected Load:		0.54 kVA		0.72 kVA		0.54 kVA						
Feed-Thru Load:		0 kVA		0 kVA		0 kVA						
Total Amps:		4.5 A		6 A		4.5 A						
Load Classification												
(Nc) Non-Continuous												
		0.36 kVA		100.00%		0.36 kVA		Connected Load: 1.80 kVA				
(R) Receptacle		1.44 kVA		100.00%		1.44 kVA		Connected Amps: 5 A				
								Code Demand Load: 1.8 kVA				
								Code Demand Amps: 5 A				
Notes: TOTAL LOADS ARE UNKNOWN.												

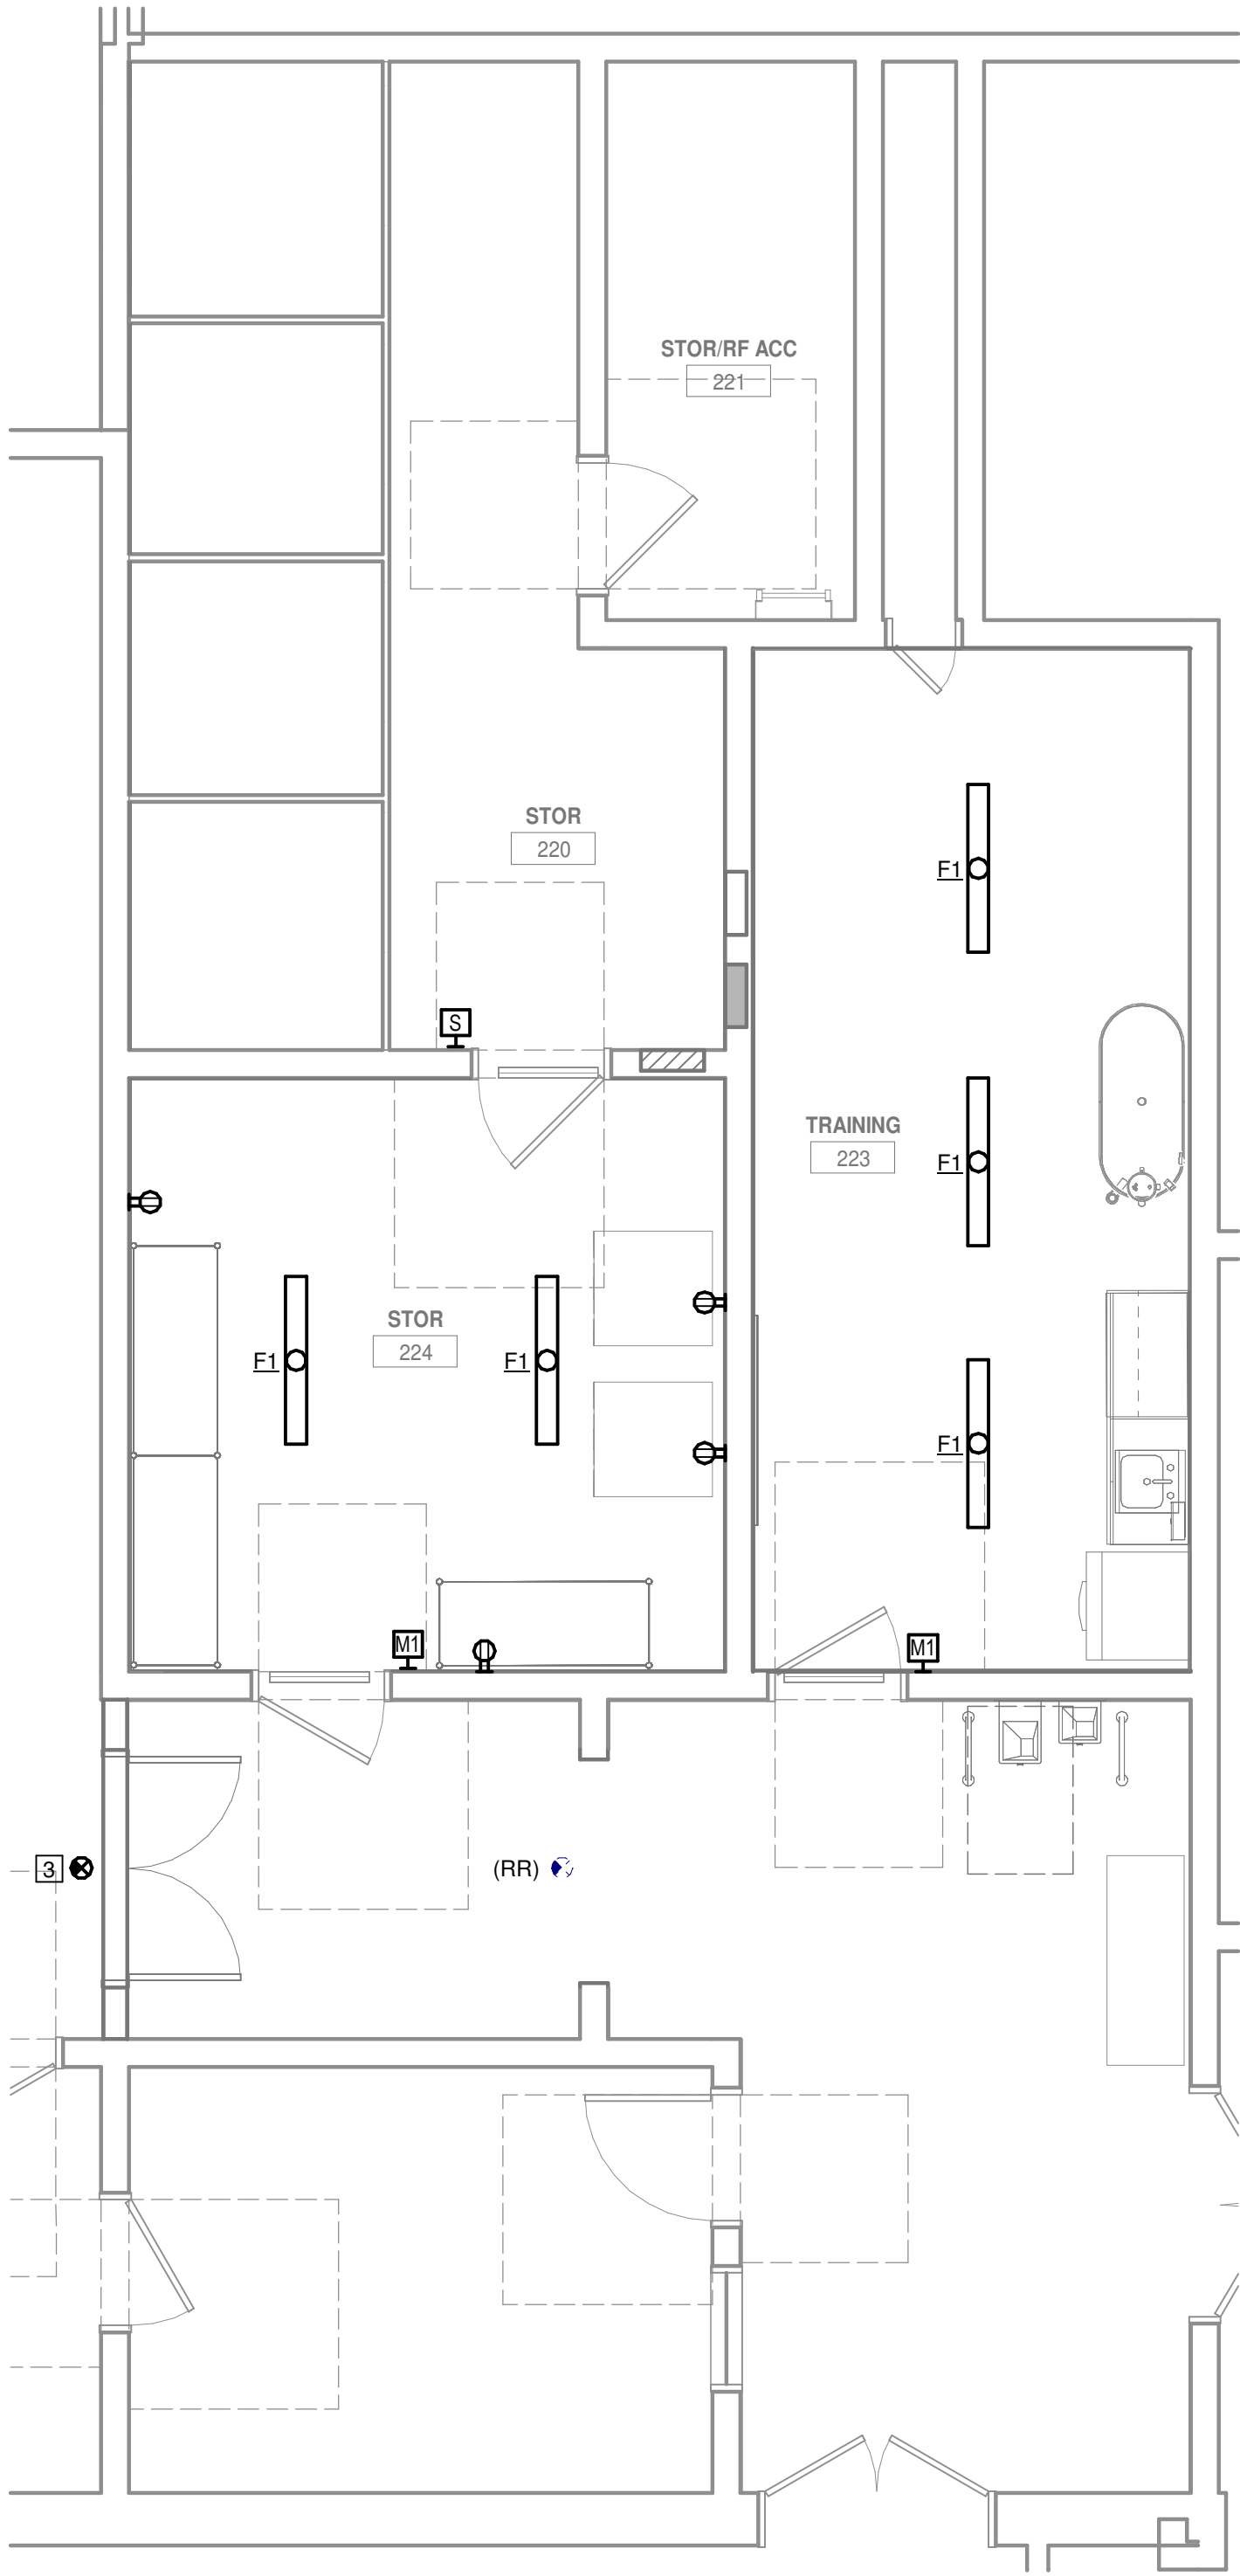

2 LIGHTING PLAN
SCALE: 1/4" = 1'-0"

GENERAL SHEET NOTES

- A. REPLACE ALL EXISTING RECEPTACLES AND FACEPLATES WITH NEW. LABEL WITH PANEL AND CIRCUIT. EXISTING RECEPTACLES ARE NOT GFCI AND SHALL BE REPLACED WITH DEDICATED GFCI RECEPTACLES AT EACH LOCATION.
- B. REMOVE EXISTING LIGHT FIXTURES AND REPLACE.

NUMBERED SHEET NOTES

- 1 EXISTING FIRE ALARM NOTIFICATION APPLIANCE TO REMAIN. REMOVE OR PROTECT DURING CONSTRUCTION AND TEST AFTER COMPLETION.
- 2 EXISTING CLOCK/PA TO REMAIN. REMOVE OR PROTECT DURING CONSTRUCTION AND TEST AFTER COMPLETION.
- 3 RELOCATE EXISTING EXIT SIGN TO LOCATION INDICATED.

LIONAKIS

2025 Nineteenth Street
Sacramento CA 95818
P 916.558.1900
www.lionakis.com

CONSULTANT



SEAL

PROJECT
MCCLATCHY HS TRAINING ROOMS

1305 Marina Village Parkway

CLIENT
Owner


ISSUED
MARK DATE DESCRIPTION

MANAGEMENT
LIONAKIS PROJECT NO.: Project Number
COPYRIGHT: LIONAKIS 2017

TITLE
POWER AND LIGHTING PLAN

SHEET

E1.0

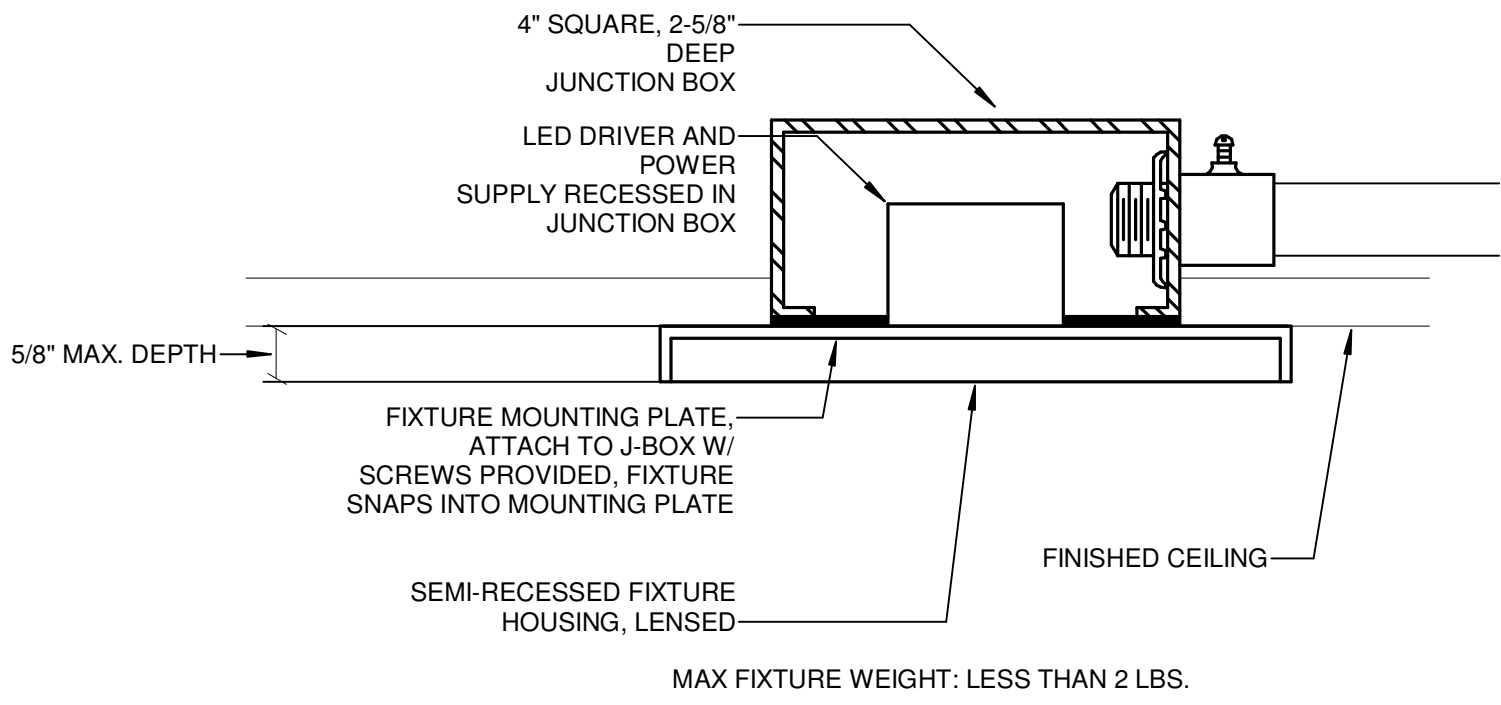

1 SEMI-RECESSED FIXTURE
SCALE: NTS

MCCLATCHY HS TRAINING ROOMS

1305 Marina Village Parkway

REVISIONS	
#	DESCRIPTION
	DATE

DESIGNER: Designer
SCALE: NTS
DATE: 2024.01.20
TITLE: DETAILS
DRAWING NO. E2.0