


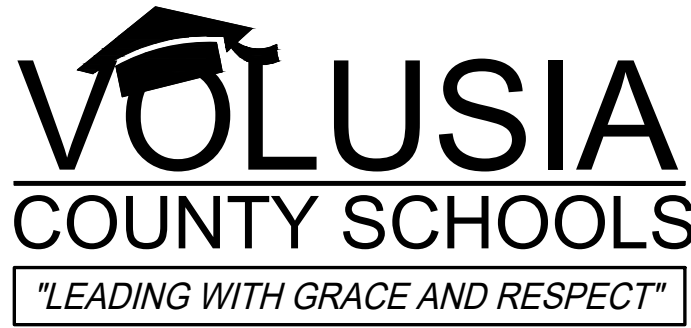

THE SCHOOL BOARD OF VOLUSIA
COUNTY FLORIDA
200 North Clara Avenue
DeLand, Florida 32720

HOLLY HILL SCHOOL REPLACE BOILER

VCS Project NO. 2648219

1500 CENTER AVENUE,
HOLLY HILL, FL. 32117

SCHOOL BOARD MEMBERS

RUBEN COLÓN
KRISTA GOODRICH
DONNA BROSEMER
JAMIE HAYNES
JESSIE THOMPSON

BOARD CHAIR
VICE BOARD CHAIR
MEMBER
MEMBER
MEMBER

DR. CARMEN J. BALGOBIN

SUPERINTENDENT

DESCRIPTION OF WORK

REMOVAL AND REPLACEMENT OF BOILERS AND GAS WATER HEATER


TO THE BEST OF OUR KNOWLEDGE, THESE DRAWINGS AND SPECIFICATIONS ARE COMPLETE AND COMPLY WITH THE FOLLOWING CODES AND THEIR REVISIONS:

8TH EDITION OF THE 2023 FLORIDA BUILDING CODE - BUILDING (FBCB)
8TH EDITION OF THE 2023 FLORIDA BUILDING CODE - EXISTING BUILDING (FBCEB)
8TH EDITION OF THE 2023 FLORIDA BUILDING CODE - ACCESSIBILITY (FBCA)
8TH EDITION OF THE 2023 FLORIDA BUILDING CODE - ENERGY CONSERVATION (FBCEC)
8TH EDITION OF THE 2023 FLORIDA BUILDING CODE - MECHANICAL (FBCM)
8TH EDITION OF THE 2023 FLORIDA BUILDING CODE - PLUMBING (FBCEP)
8TH EDITION OF THE 2023 FLORIDA BUILDING CODE - FUEL GAS (FBCFG)
8TH EDITION OF THE 2023 FLORIDA FIRE PREVENTION CODE (FFPC)
NFPA 70 - 2020 NATIONAL ELECTRICAL CODE (NEC)
2014 STATE REQUIREMENTS FOR EDUCATIONAL FACILITIES (SREF)
VOLUSIA COUNTY SCHOOL DISTRICT DESIGN STANDARDS

BUILDING DATA

A. SURVEY PARCEL ID	XXX
B. LEGAL DESCRIPTION	XXX
C. OCCUPANCY TYPE	XXX
D. CONSTRUCTION TYPE	TYPE XXX
E. RISK CATEGORY	XXX
F. AUTOMATIC SPRINKLER	XXX
G. BUILDING AREA	XXX
H. BUILDING HEIGHT	XXX
I. OCCUPANT LOAD	XXX

LOCATION MAP

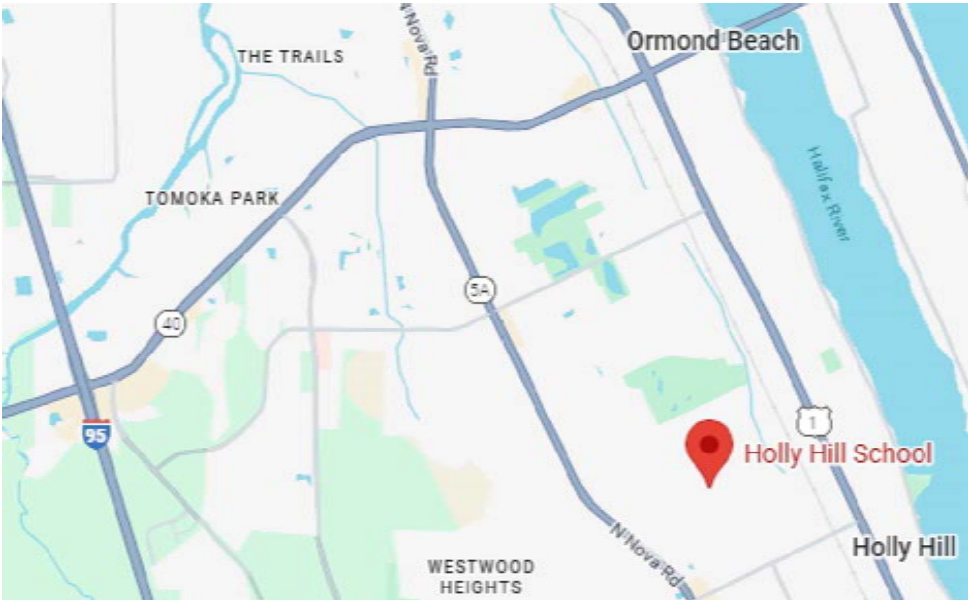

NOT TO SCALE

ENGINEERS & CONSULTANTS

ENGINEERING
DAVID A. DASILVA
4083 SOUTH U.S. HIGHWAY 1, SUITE. 101
ROCKLEDGE, FLORIDA 32955
PHONE 321.633.4522
DASILVA.DAVID@DDC-ENGINEERS.COM
WWW.DDC-ENGINEERS.COM



SHT NO	TITLE
G001	COVER SHEET
M001	MECHANICAL LEGEND & NOTES
MD100	MECHANICAL DEMOLITION PLANS
M100	MECHANICAL PLANS
M500	MECHANICAL DETAILS
M600	MECHANICAL SCHEDULES
E001	ELECTRICAL LEGEND & NOTES
E100	ELECTRICAL PLANS
E500	ELECTRICAL DETAILS
E600	ELECTRICAL SCHEDULE & ONE-LINE DIAGRAM
P001	PLUMBING LEGEND & NOTES
PD100	PLUMBING DEMOLITION PLANS
P100	PLUMBING PLANS
P500	PLUMBING DETAILS & RISERS

CONSTRUCTION DOCUMENTS - 03/27/2026



4083 South U.S. Highway 1, Ste. 101
Rockledge, Florida 32955
Phone 321.633.4522 Fax 321.633.4528
www.ddc-engineers.com
dasilva.david@ddc-engineers.com
C.O.A.: 25988
DDC PROJECT NO.: 25007.01

David A. DaSilva
54739

THIS ITEM HAS BEEN DIGITALLY SIGNED AND SEALED BY DAVID A. DASILVA ON THE DATE ADJACENT TO THE SEAL. PRINTED COPIES OF THIS DOCUMENT ARE NOT CONSIDERED SIGNED AND SEALED AND THE SIGNATURE MUST BE VERIFIED ON ANY ELECTRONIC COPIES.

REVISIONS

DOCUMENT HISTORY
DESCRIPTION
NO. DATE

HOLLY HILL SCHOOL
REPLACE BOILER
VCS Project NO. 2648219
1500 CENTER AVENUE,
HOLLY HILL, FL. 32117

ENGINEER DAVID A. DASILVA	
DESIGNED BY DAD	DRAWN BY IO/HR
ISSUE DATE 03/27/2026	AE PROJECT NUMBER 25007.01
SHEET TITLE COVER SHEET	
DRAWING NO. G001	

MECHANICAL SYMBOLS LEGEND, NOTES, AND REQUIREMENTS

HVAC LEGEND

	DOUBLE LINE DUCTWORK, FIRST DIMENSION IS SIDE SHOWN.
	SINGLE LINE DUCTWORK, FIRST DIMENSION IS SIDE SHOWN.
	ITEM(S) TO BE REMOVED
	ELECTRIC DUCT HEATER
	FLEX DUCTWORK
	OUTSIDE AIR LOUVER
	OUTSIDE AIR ROOF INTAKE
	DUCT UP TO OUTSIDE AIR ROOF INTAKE ABOVE
	EXHAUST AIR ROOF VENT
	DUCT UP TO EXHAUST AIR ROOF VENT ABOVE
	ROOF TOP EXHAUST FAN
	DUCT UP TO ROOF TOP EXHAUST FAN ABOVE
	CEILING DIFFUSER, ROUND NECK (CEILING DIFFUSERS ARE 4-WAY THROW UON)
	ROUND DIFFUSER
	CEILING RETURN GRILLE WITH SQUARE CONNECTION
	CEILING RETURN GRILLE WITH ROUND CONNECTION
	CEILING EXHAUST GRILLE
	EXHAUST FAN
	SIDE WALL DIFFUSER
	SIDE WALL RETURN
	THERMOSTAT/TEMPERATURE SENSOR
	HUMIDISTAT/HUMIDITY SENSOR
	PHOTOELECTRIC DUCT SMOKE DETECTOR R=RETURN S=SUPPLY
	MOTORIZED CONTROL DAMPER
	TEMPERATURE SENSOR
	PRESSURE SENSOR
	BACKDRAFT DAMPER
	CEILING MOUNTED ACCESS DOOR
	90° ELBOW W/TURNING VANES
	RADIUS ELBOW W/O TURNING VANES
	FIRE DAMPER (WITH ACCESS PANEL)
	FIRE & SMOKE DAMPER (WITH ACCESS PANEL)
	SMOKE DAMPER (WITH ACCESS PANEL)
	MANUAL BALANCING DAMPER
	ROUND SPIRAL
	DOUBLE LINE ROUND DUCTSOCK
	SINGLE LINE ROUND DUCTSOCK
	ZONE DAMPER
	VARIABLE AIR VOLUME (VAV) BOX W/ NO HEAT
	VARIABLE AIR VOLUME (VAV) BOX W/ HEAT
	IN-LINE EXHAUST FAN
	CONDENSER UNIT
	VERTICAL AC UNIT
	HORIZONTAL AC UNIT
	HORIZONTAL HEAT PUMP UNIT
	PACKAGED ROOFTOP OR GROUND MOUNTED AC UNIT

HVAC PIPING LEGEND

	CHS CHILLED WATER SUPPLY
	CHR CHILLED WATER RETURN
	CWS CONDENSER WATER SUPPLY
	CWR CONDENSER WATER RETURN
	REF REFRIGERANT PIPING
	CD CONDENSATE
	HWS HOT WATER SUPPLY
	FLOW DIRECTION
	GATE VALVE OR BALL VALVE
	CALIBRATING BALANCING VALVE
	BUTTERFLY VALVE
	STRAINER
	CONTROL VALVE
	UNION
	CHECK VALVE
	THERMOMETER
	CONNECTION, BOTTOM
	CONNECTION, TOP

MISCELLANEOUS

	SHEET NOTE CALLOUT
	REVISION REFERENCE
	LIGHT DASHED INDICATES EXISTING FIXTURE OR DEVICE
	DARK DASHED INDICATES EXISTING FIXTURE OR DEVICE RELOCATED
	DARK SOLID INDICATES NEW FIXTURE OR DEVICE
	HATCHED ITEMS INDICATES FIXTURE OR DEVICE TO BE REMOVED OR RELOCATED
	NOT IN CONTRACT (N.I.C.)
	POINT OF CONNECTION
	POINT OF DISCONNECT
	NEW CFM
	EXISTING CFM
	EQUIPMENT TAG

ABBREVIATIONS

ABV - ABBREVIATION	HZ - HERTZ
AC - AIR CONDITIONER	IN - INCHES
AF - ABOVE FINISHED FLOOR	IW - INDIRECT WASTE
AFG - ABOVE FINISHED GRADE	KEF - KITCHEN EXHAUST FAN
AHU - AIR HANDLING UNIT	KSF - KITCHEN SUPPLY FAN
AP - ACCESS PANEL	KW - KILOWATT
AS - AIR SEPARATOR	LAT - LEAVING AIR TEMPERATURE
BD - BYPASS DAMPER	LF - LINEAR FOOT
BDP - BOTTOM OF PIPE	LWT - LEAVING WATER TEMPERATURE
BHP - BRAKE HORSE POWER	LD - LINEAR DIFFUSER
BTUH - BRITISH THERMAL UNIT	LQ - LIQUID
CAP - CAPACITY	LP - LOOP PUMPS
CD - CONDENSATE DRAIN	MAU - MAKE-UP AIR UNIT
CFM - CUBIC FEET PER MINUTE	MAX - MAXIMUM
CH - CHILLER	MBH - THOUSAND BTU PER HOUR
CHP - CHILLED WATER PUMP	MCA - MINIMUM CIRCUIT AMPACITY
CHR - CHILLED WATER RETURN	MECH - MECHANICAL
CHS - CHILLED WATER SUPPLY	MIN - MINIMUM
COMB - COMBINATION	MD - MOTORIZED DAMPER
CONN - CONNECTION	NC - NORMALLY CLOSED
CONT - CONTINUE	NFPA - NATIONAL FIRE PROTECTION ASSOCIATION
CT - COOLING TOWER	NO - NORMALLY OPEN
CW - COLD WATER	NOM - NOMINAL
CWP - CONDENSER WATER PUMP	NTS - NOT TO SCALE
CWS - CONDENSER WATER SUPPLY	OA - OUTSIDE AIR
CWR - CONDENSER WATER RETURN	OAU - OUTSIDE AIR UNIT
CU - CONDENSING UNIT	OC - ON CENTER
DB - DRY BULB	PD - PRESSURE DROP
DIA - DIAMETER	PH - PHASE
DG - DOOR GRILLE	PRV - PRESSURE REDUCING VALVE
DL - DOOR LOUVER	PSI - POUNDS PER SQUARE INCH
DN - DOWN	PSIG - PSI GAUGE
DP - DIFFERENTIAL PRESSURE	PTAC - PACKAGED TERMINAL AIR CONDENSER
DWG - DRAWING	PVC - POLYVINYL CHLORIDE PIPE
EA - EXHAUST AIR	QTY - QUANTITY
EAT - ENTERING AIR TEMPERATURE	RA - RETURN AIR
EDH - ELECTRIC DUCT HEATER	REF - REFRIGERANT
EER - ENERGY EFFICIENCY RATIO	RG - RETURN GRILLE
EF - EXHAUST FAN	RPM - REVOLUTIONS PER MINUTE
EFF - EFFICIENCY	RLA - RATED LOAD AMPS
EG - EXHAUST GRILLE	RTU - ROOF TOP UNIT
ENT - ENTERING	SA - SUPPLY AIR
ESP - EXTERNAL STATIC PRESSURE	SEER - SEASONAL ENERGY EFFICIENCY RATING
ET - EXPANSION TANK	SEN - SENSIBLE
EWT - ENTERING WATER TEMPERATURE	SD - SMOKE DAMPER
EXP - EXPANSION	SP - STATIC PRESSURE
FA - FACE AREA	SWD - SIDEWALL DIFFUSER
FCU - FAN COIL UNIT	SWR - SIDEWALL RETURN
FD - FIRE DAMPER	T - THERMOSTAT
FLA - FULL LOAD AMPS	TEMP - TEMPERATURE
FLEX - FLEXIBLE	TG - TRANSFER GRILLE
FPM - FEET PER MINUTE	TSH - TOTAL SENSIBLE HEAT
FS - FLOOR SINK	TSP - TOTAL STATIC PRESSURE
FT - FEET	TYP - TYPICAL
FV - FACE VELOCITY	UC - UNDER CUT
GA - GAUGE	UG - UNDER GROUND
GPM - GALLONS PER MINUTE	UON - UNLESS OTHERWISE NOTED
HP - HORSE POWER	VAV - VARIABLE AIR VOLUME
HB - HOSE BIBB	VLV - VALVE
HR - HOUR	VSD - VARIABLE SPEED DRIVE
HW - HOT WATER	WB - WET BULB
HWR - HOT WATER RETURN	ZD - ZONE DAMPER
HWS - HOT WATER SUPPLY	ΔT - CHANGE IN TEMPERATURE
	ΔP - CHANGE IN PRESSURE

GENERAL NOTES

1. VERIFY THAT ALL EQUIPMENT, AS SHOWN ON THESE DRAWINGS, WILL NOT CONFLICT WITH ANY DRAINS, SCUTTLES, JOINTS, VENTS, PIPING OR OTHER EQUIPMENT PRIOR TO INSTALLATION.
2. EQUIPMENT SUPPLIER SHALL PROVIDE COMPLETE INFORMATION AND COOPERATE WITH THE OWNER'S REPRESENTATIVE AS REQUIRED FOR PROJECT COMPLETION AND COORDINATION.
3. CONTRACTOR SHALL ADMINISTER AND SUBMIT ALL DRAWINGS FOR PERMITTING.
4. ALL OUTSIDE AIR INTAKES SHALL BE A MINIMUM OF 10'-0" FROM ANY EXHAUST FAN, GAS OR PLUMBING VENT.
5. PROVIDE VIBRATION ISOLATION DEVICES AND FLEXIBLE CONNECTIONS TO ALL MOVING MACHINERY.
6. ALL PIPE AND DUCTWORK DIMENSIONS SHOWN ON DRAWINGS ARE CLEAR INSIDE DIMENSIONS.
7. COORDINATE WITH ALL OTHER TRADES, ALL REQUIRED OPENINGS AND ROOF PENETRATIONS. ALL REQUIRED OPENINGS IN FOUNDATIONS, FLOORS, WALLS AND ROOF SHALL BE MADE AND INSTALLED INTO THE STRUCTURE WITH THE USE OF SLEEVES, CURBS, ETC.
8. PROVIDE SHOP DRAWINGS FOR ALL HVAC EQUIPMENT AND MATERIALS.
9. CONTROL PANELS AND REMOTE SENSORS SHALL BE LOCATED GENERALLY AS SHOWN. EXACT LOCATIONS SHALL BE FIELD COORDINATED TO AVOID INTERFERENCE WITH WALL MOUNTED WORK.
10. FURNISH AND INSTALL 4" HIGH BLACK NAMEPLATES FOR ALL EQUIPMENT.
11. FIELD VERIFY ALL EXISTING SERVICES PRIOR TO START OF CONSTRUCTION.
12. REMOVE EXISTING CEILINGS, GRID, CEILING DEVICES, ETC., TO INSTALL NEW HVAC SYSTEMS. REINSTALL OR PROVIDE NEW CEILING GRID AND TILE, TO MATCH EXISTING CONDITIONS. REINSTALL EXISTING CEILING DEVICES.
13. CONTRACTOR SHALL BE RESPONSIBLE FOR THE REMOVAL OF EXISTING CEILING, WALLS, SLABS, ETC. TO INSTALL NEW SYSTEM. MINIMIZE SAW CUTTING OF WALLS, SLABS, ETC. PATCH AND REPAIR ALL SURFACES IMPACTED BY CONSTRUCTION. PAINT ALL SURFACE TO MATCH EXISTING FINISH.

GENERAL DEMOLITION NOTES

- A. THE CONTRACTOR SHALL VISIT AND CAREFULLY EXAMINE THOSE PORTIONS OF THE BUILDING AND SITE AFFECTED BY THIS WORK BEFORE SUBMITTING PROPOSAL SO AS TO BECOME FAMILIAR WITH EXISTING WORK. SUBMISSION OF A PROPOSAL WILL BE CONSIDERED AS EVIDENCE THAT SUCH EXAMINATION HAS BEEN MADE AND LATER CLAIMS FOR LABOR, EQUIPMENT OR MATERIALS REQUIRED BECAUSE OF BY DIFFICULTIES ENCOUNTERED WILL NOT BE RECOGNIZED. IT IS TO BE UNDERSTOOD THAT UNFORESEEN CONDITIONS PROBABLY EXIST AND NEW WORK MAY NOT BE FIELD LOCATED EXACTLY AS SHOWN ON THE DRAWINGS. COOPERATION WITH OTHER TRADES IN EQUIPMENT REMOVAL AS DETERMINED DURING CONSTRUCTION AND AS DIRECTED BY THE ARCHITECT/ENGINEER MAY BE NECESSARY AND IT IS INTENDED THAT SUCH DEVIATIONS SHALL BE CONSIDERED AS PART OF THIS CONTRACT. IT IS ALSO UNDERSTOOD THAT THE PLANS ARE NOT COMPLETELY TO SCALE. THIS CONTRACTOR IS TO FIELD VERIFY DIMENSIONS OF ALL EXISTING CONDITIONS, PRIOR TO BID AND INCLUDE ANY DEVIATIONS IN THE CONTRACT.
- B. ALL DEVICES AND EQUIPMENT NOT SHOWN AND IN AREAS OUTSIDE OF REMODELING SHALL REMAIN ACTIVE UNLESS OTHERWISE NOTED. INSTALL AS REQUIRED TO MAINTAIN CONTINUITY TO EXISTING DEVICES AND EQUIPMENT THAT ARE TO REMAIN.
- C. ALL EQUIPMENT AND MATERIAL REMOVED AND NOT REUSED SHALL BE TURNED OVER TO THE OWNER OR AT THE OWNER'S REQUEST LEGALLY DISPOSED OF BY THE CONTRACTOR.
- D. ALL HVAC DEVICES, EQUIPMENT, DUCTWORK, ETC., THAT ARE REMOVED SHALL BE REMOVED AS DIRECTED BY THE OWNER/ENGINEER. AND CEILING OR WALL SHALL BE PATCHED TO MATCH EXISTING OR NEW FINISH. ALL PATCHES SHALL BE PATCHED OR PAINTED AS DIRECTED BY ARCHITECTURAL DRAWINGS.
- E. ALL EXISTING HVAC EQUIPMENT, DUCTWORK, DEVICES, ETC., IS NOT SHOWN. IT IS THE CONTRACTORS RESPONSIBILITY TO BECOME FAMILIAR WITH ALL EXISTING CONDITIONS PRIOR TO BID, AND INCLUDE IN HIS BID THE REMOVAL OF ALL EQUIPMENT, DUCTWORK, DEVICES, ETC., THAT IS NOT BEING REUSED BACK TO ITS SOURCE.
- F. ALL CONCRETE, WALL PATCHING, CEILING REPAIR, AND OTHER GENERAL WORK REQUIRED FOR INSTALLING THE HVAC SYSTEMS AND TO REPAIR TO "LIKE NEW CONDITION" TO BE PROVIDED AND INSTALLED BY THE CONTRACTOR.
- G. PROVIDE AND INSTALL ANY ADDITIONAL HANGERS/SUPPORTS REQUIRED TO ACCOMMODATE ANY EQUIPMENT RELOCATIONS.
- H. COORDINATE ALL CEILING MOUNTED DEVICES WITH ARCHITECTURAL REFLECTED CEILING AND WORK OF ALL OTHER TRADES.
- I. ITEMS NOTED AS EXISTING TO BE REMOVED COMPLETELY. REMOVAL SHALL INCLUDE ALL DEVICES, PIPING, HANGERS, SUPPORTS, ETC.

SHOP DRAWING SUBMITTALS

ITEM	COPY FOR OWNER REVIEW	PRODUCT DATA				SHOP DRAWINGS		TEST REPORTS		COORDINATION DRAWINGS		WIRING DIAGRAMS		O & M MANUAL	
		1	2	3	4	1	2	1	2	1	2	1	2	1	2
BOILER EQUIPMENT	X	X	X	X	X	X	X	X	X	X	X	X	X	X	X
INSULATION	X	X	X	X	X	X	X	X	X	X	X	X	X	X	X
PIPING	X	X	X	X	X	X	X	X	X	X	X	X	X	X	X
CONTROLS	X	X	X	X	X	X	X	X	X	X	X	X	X	X	X
ELECTRIC DISCONNECTS	X	X	X	X	X	X	X	X	X	X	X	X	X	X	X
DUCTWORK/SUPPORTS	X	X	X	X	X	X	X	X	X	X	X	X	X	X	X

NOTES: 1- FOR REVIEW 2- FOR RECORD 3- COLOR SELECTION 4- SAMPLE	NOTE: FOR ALL MATERIALS FOR CONSTRUCTION, INSTALLATION REQUIREMENTS AND TESTING REQUIREMENTS, REFER TO CONTRACT SPECIFICATIONS. CONTRACTOR SHALL SUBMIT ALL ITEMS UNDER ONE SUBMITTAL THAT REFERENCES DDC PROJECT NUMBER. NO PARTIAL SUBMITTALS WILL BE ACCEPTED. ALL SUBMITTALS SHALL BE EMAILED TO INFO@DDC-ENGINEERS.COM .
---	---

DESIGN CRITERIA

DESIGN TEMPERATURES:

OUTDOOR AIR:	
SUMMER:	95°F DB/80°F WB
WINTER:	30°F DB
INDSIDE AIR:	
SUMMER:	75°F DB/60% RH
WINTER:	72°F DB

NOTES:
THE DESIGN CRITERIA ABOVE IS BASED ON ASHRAE STANDARD 62.1. ANY CHANGES TO THIS OCCUPANCY OR FLOOR PLAN WILL REQUIRE FURTHER REVIEW AND MODIFICATIONS TO THIS VENTILATION SYSTEM.

CODE COMPLIANCE REQUIREMENTS

ALL WORK SHALL BE IN COMPLIANCE WITH THE FOLLOWING CODES, BUT NOT LIMITED TO:
8TH EDITION OF THE 2023 FLORIDA BUILDING CODE - BUILDING (FBCB)
8TH EDITION OF THE 2023 FLORIDA BUILDING CODE - EXISTING BUILDING (FBCEB)
8TH EDITION OF THE 2023 FLORIDA BUILDING CODE - ACCESSIBILITY (FBCA)
8TH EDITION OF THE 2023 FLORIDA BUILDING CODE - ENERGY CONSERVATION (FBCEC)
8TH EDITION OF THE 2023 FLORIDA BUILDING CODE - MECHANICAL (FBCEM)
8TH EDITION OF THE 2023 FLORIDA BUILDING CODE - PLUMBING (FBCEP)
8TH EDITION OF THE 2023 FLORIDA BUILDING CODE - FUEL GAS (FBCEG)
8TH EDITION OF THE 2023 FLORIDA FIRE PREVENTION CODE (FFPC)
NFPA 70 - 2020 NATIONAL ELECTRICAL CODE (NEC)

SCOPE OF WORK

- REMOVE AND REPLACE EXISTING BOILERS.
- REMOVE AND REPLACE EXISTING WATER HEATER.
- MODIFY ELECTRICAL SERVICE TO EQUIPMENT.
- MODIFY DDC CONTROLS FOR NEW EQUIPMENT.

NOTE: CONTRACTOR SHALL BE RESPONSIBLE FOR THE REMOVAL OF DOORS AND FRAMING AS NEEDED TO INSTALL NEW EQUIPMENTS. REFER TO MECHANICAL SPECIFICATIONS FOR FURTHER REQUIREMENTS.



4083 South U.S. Highway 1, Ste. 101
Rockledge, Florida 32955
Phone 321.633.4522 Fax 321.633.4528
www.ddc-engineers.com
dasilva.david@ddc-engineers.com
C.O.A.: 25988
DDC PROJECT NO.: 25007.01

David A. DaSilva
54739

THIS ITEM HAS BEEN DIGITALLY SIGNED AND SEALED BY DAVID A. DASILVA ON THE DATE ADJACENT TO THE SEAL. PRINTED COPIES OF THIS DOCUMENT ARE NOT CONSIDERED SIGNED AND SEALED AND THE SIGNATURE MUST BE OBTAINED ON ANY ELECTRONIC COPIES.

REVISIONS

DOCUMENT HISTORY

NO. DATE DESCRIPTION

HOLLY HILL SCHOOL

REPLACE BOILER

VCS Project NO. 2648219

1500 CENTER AVENUE,
HOLLY HILL, FL. 32117

ENGINEER OF RECORD

ENGINEER
DAVID A. DASILVA

DESIGNED BY

DAD

DRAWN BY

IO/HR

ISSUE DATE

03/27/2026

AE PROJECT NUMBER

25007.01

SHEET TITLE


MECHANICAL
LEGEND, NOTES

DRAWING NO.

M001



- D1. REMOVE EXISTING BOILER.
- D2. DISCONNECT HOT WATER PIPING AND REMOVE BOILER PUMP.
- D3. REMOVE EXISTING GAS WATER HEATER.
- D4. REMOVE EXISTING VENT CONNECTION SERVING BOILER OR HEATER.
- D5. DISCONNECT BENT PIPING.
- D6. REMOVE ALL CONTROL TEMPERATURE SENSORS WITHIN PIPES BEING REPLACE.
- D7. EXISTING CONTROL SYSTEM (ALERTON) TO BE REUSED.

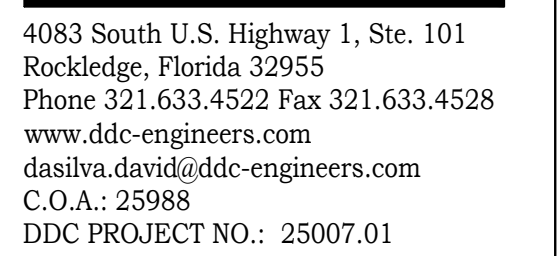


THIS ITEM HAS BEEN DIGITALLY SIGNED AND SEALED BY DAVID A. DASILVA ON THE DATE ADJACENT TO THE SEAL. PRINTED COPIES OF THIS DOCUMENT ARE NOT CONSIDERED SIGNED AND SEALED AND THE SIGNATURE MUST BE VERIFIED ON ANY ELECTRONIC COPIES.


[illegible]

**HOLLY HILL SCHOOL
REPLACE BOILER
VCS Project NO. 2648219**
1500 CENTER AVENUE,
HOLLY HILL, FL. 32117

MD100

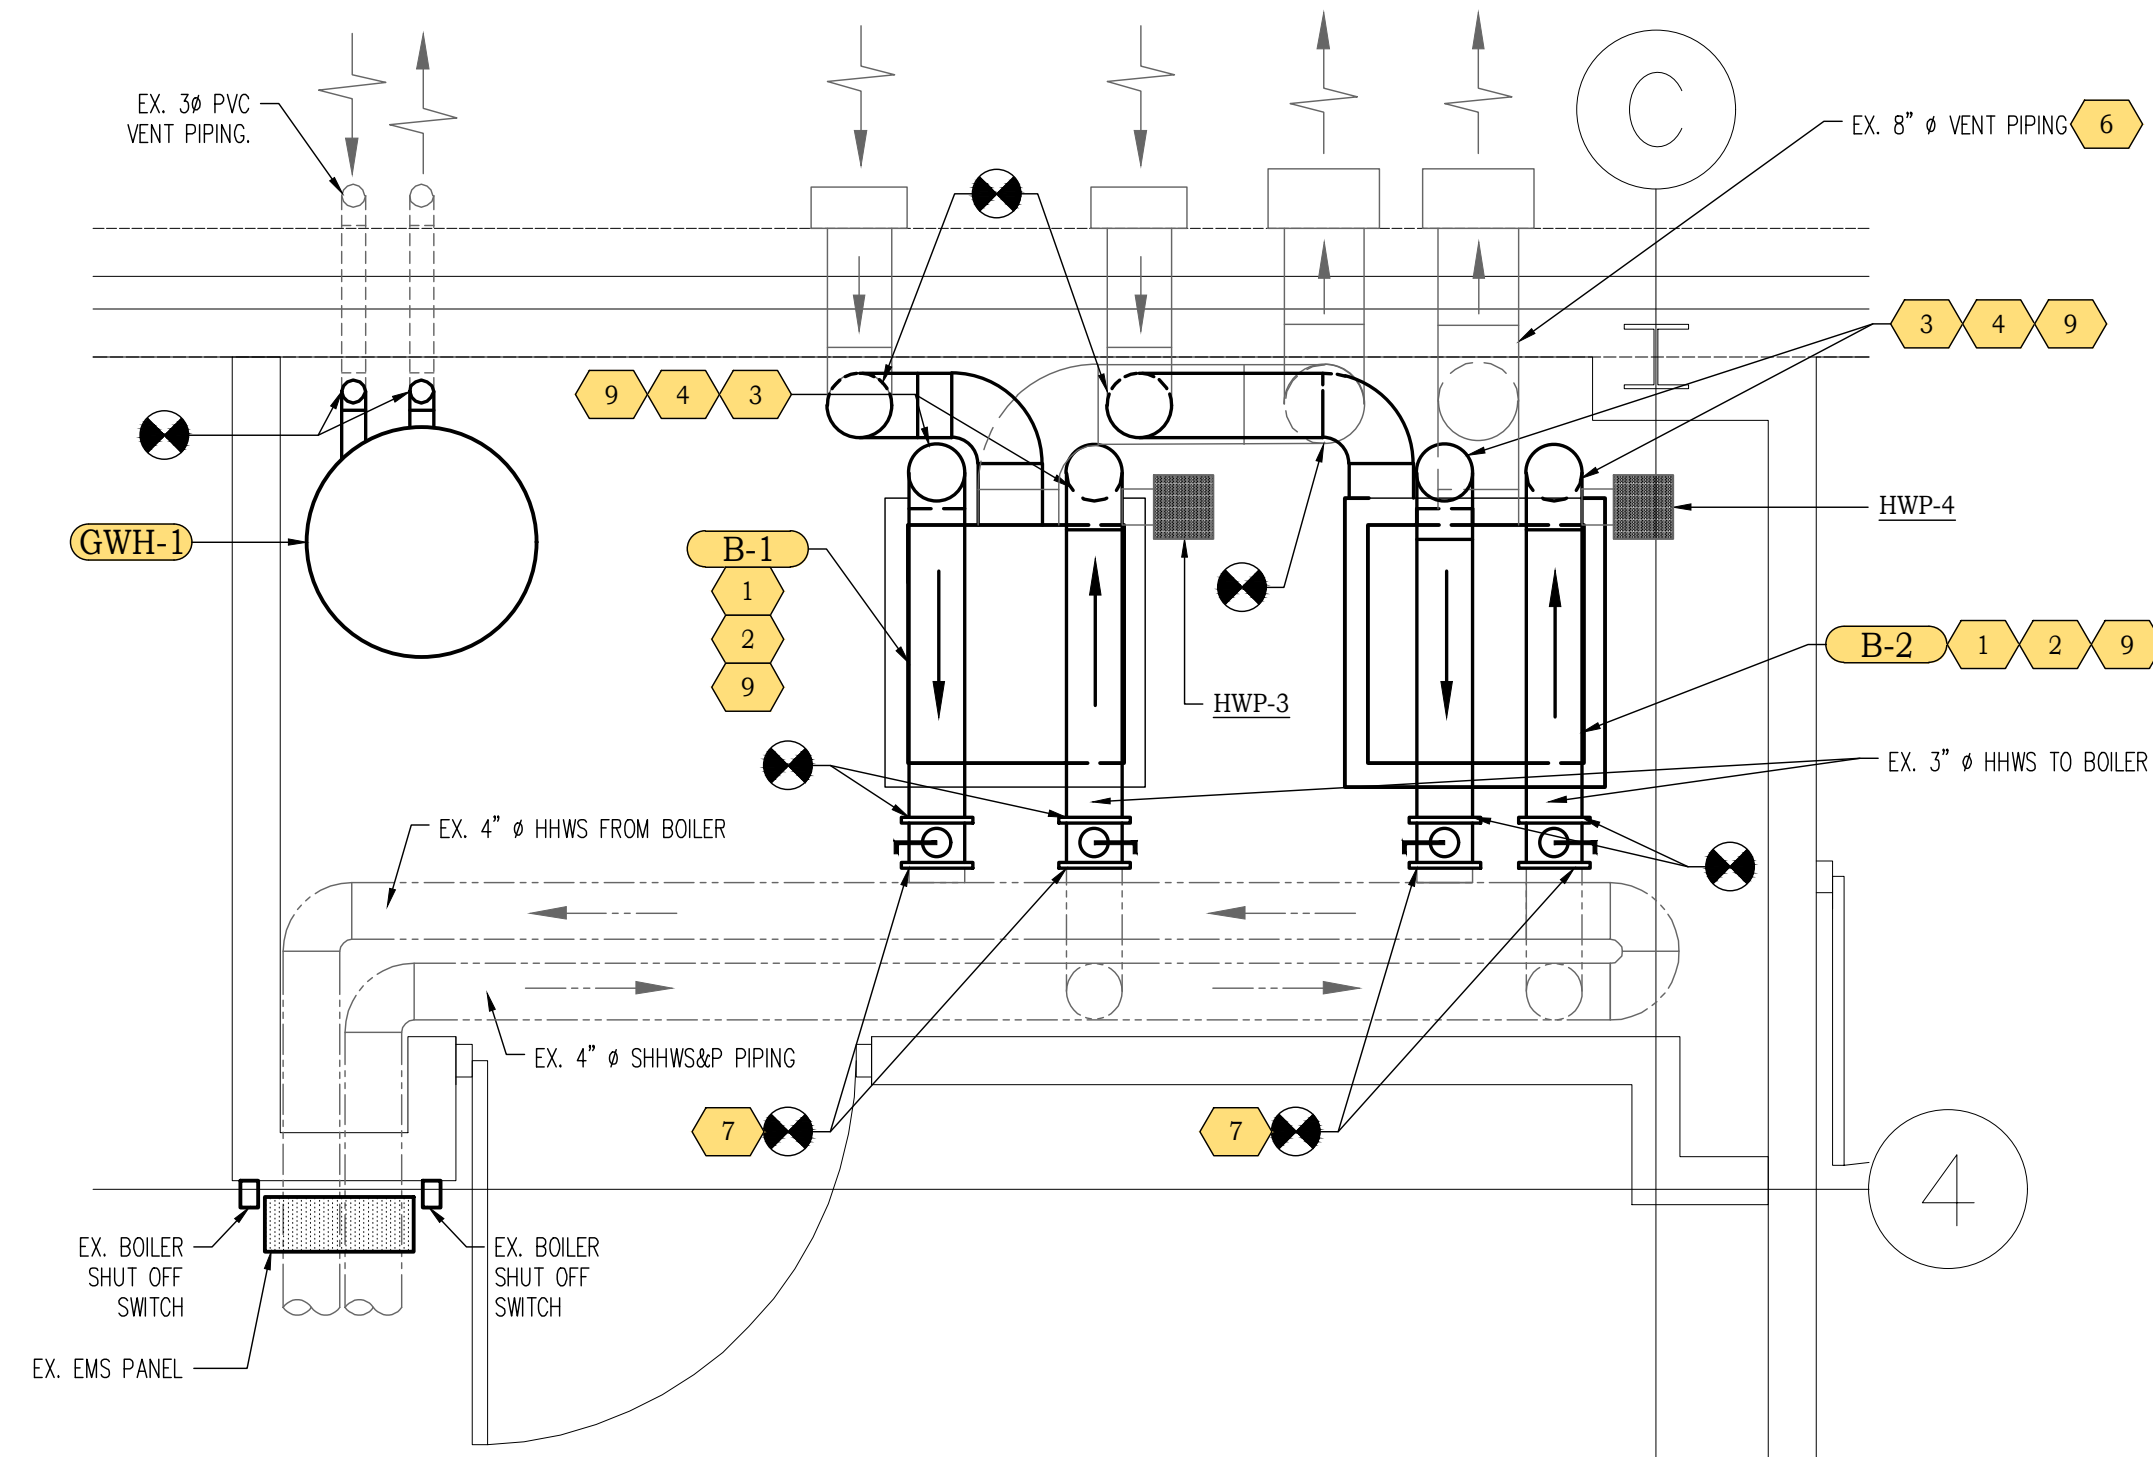

MECHANICAL PLAN
ENLARGED BOILER ROOM
1/2" = 1'-0"

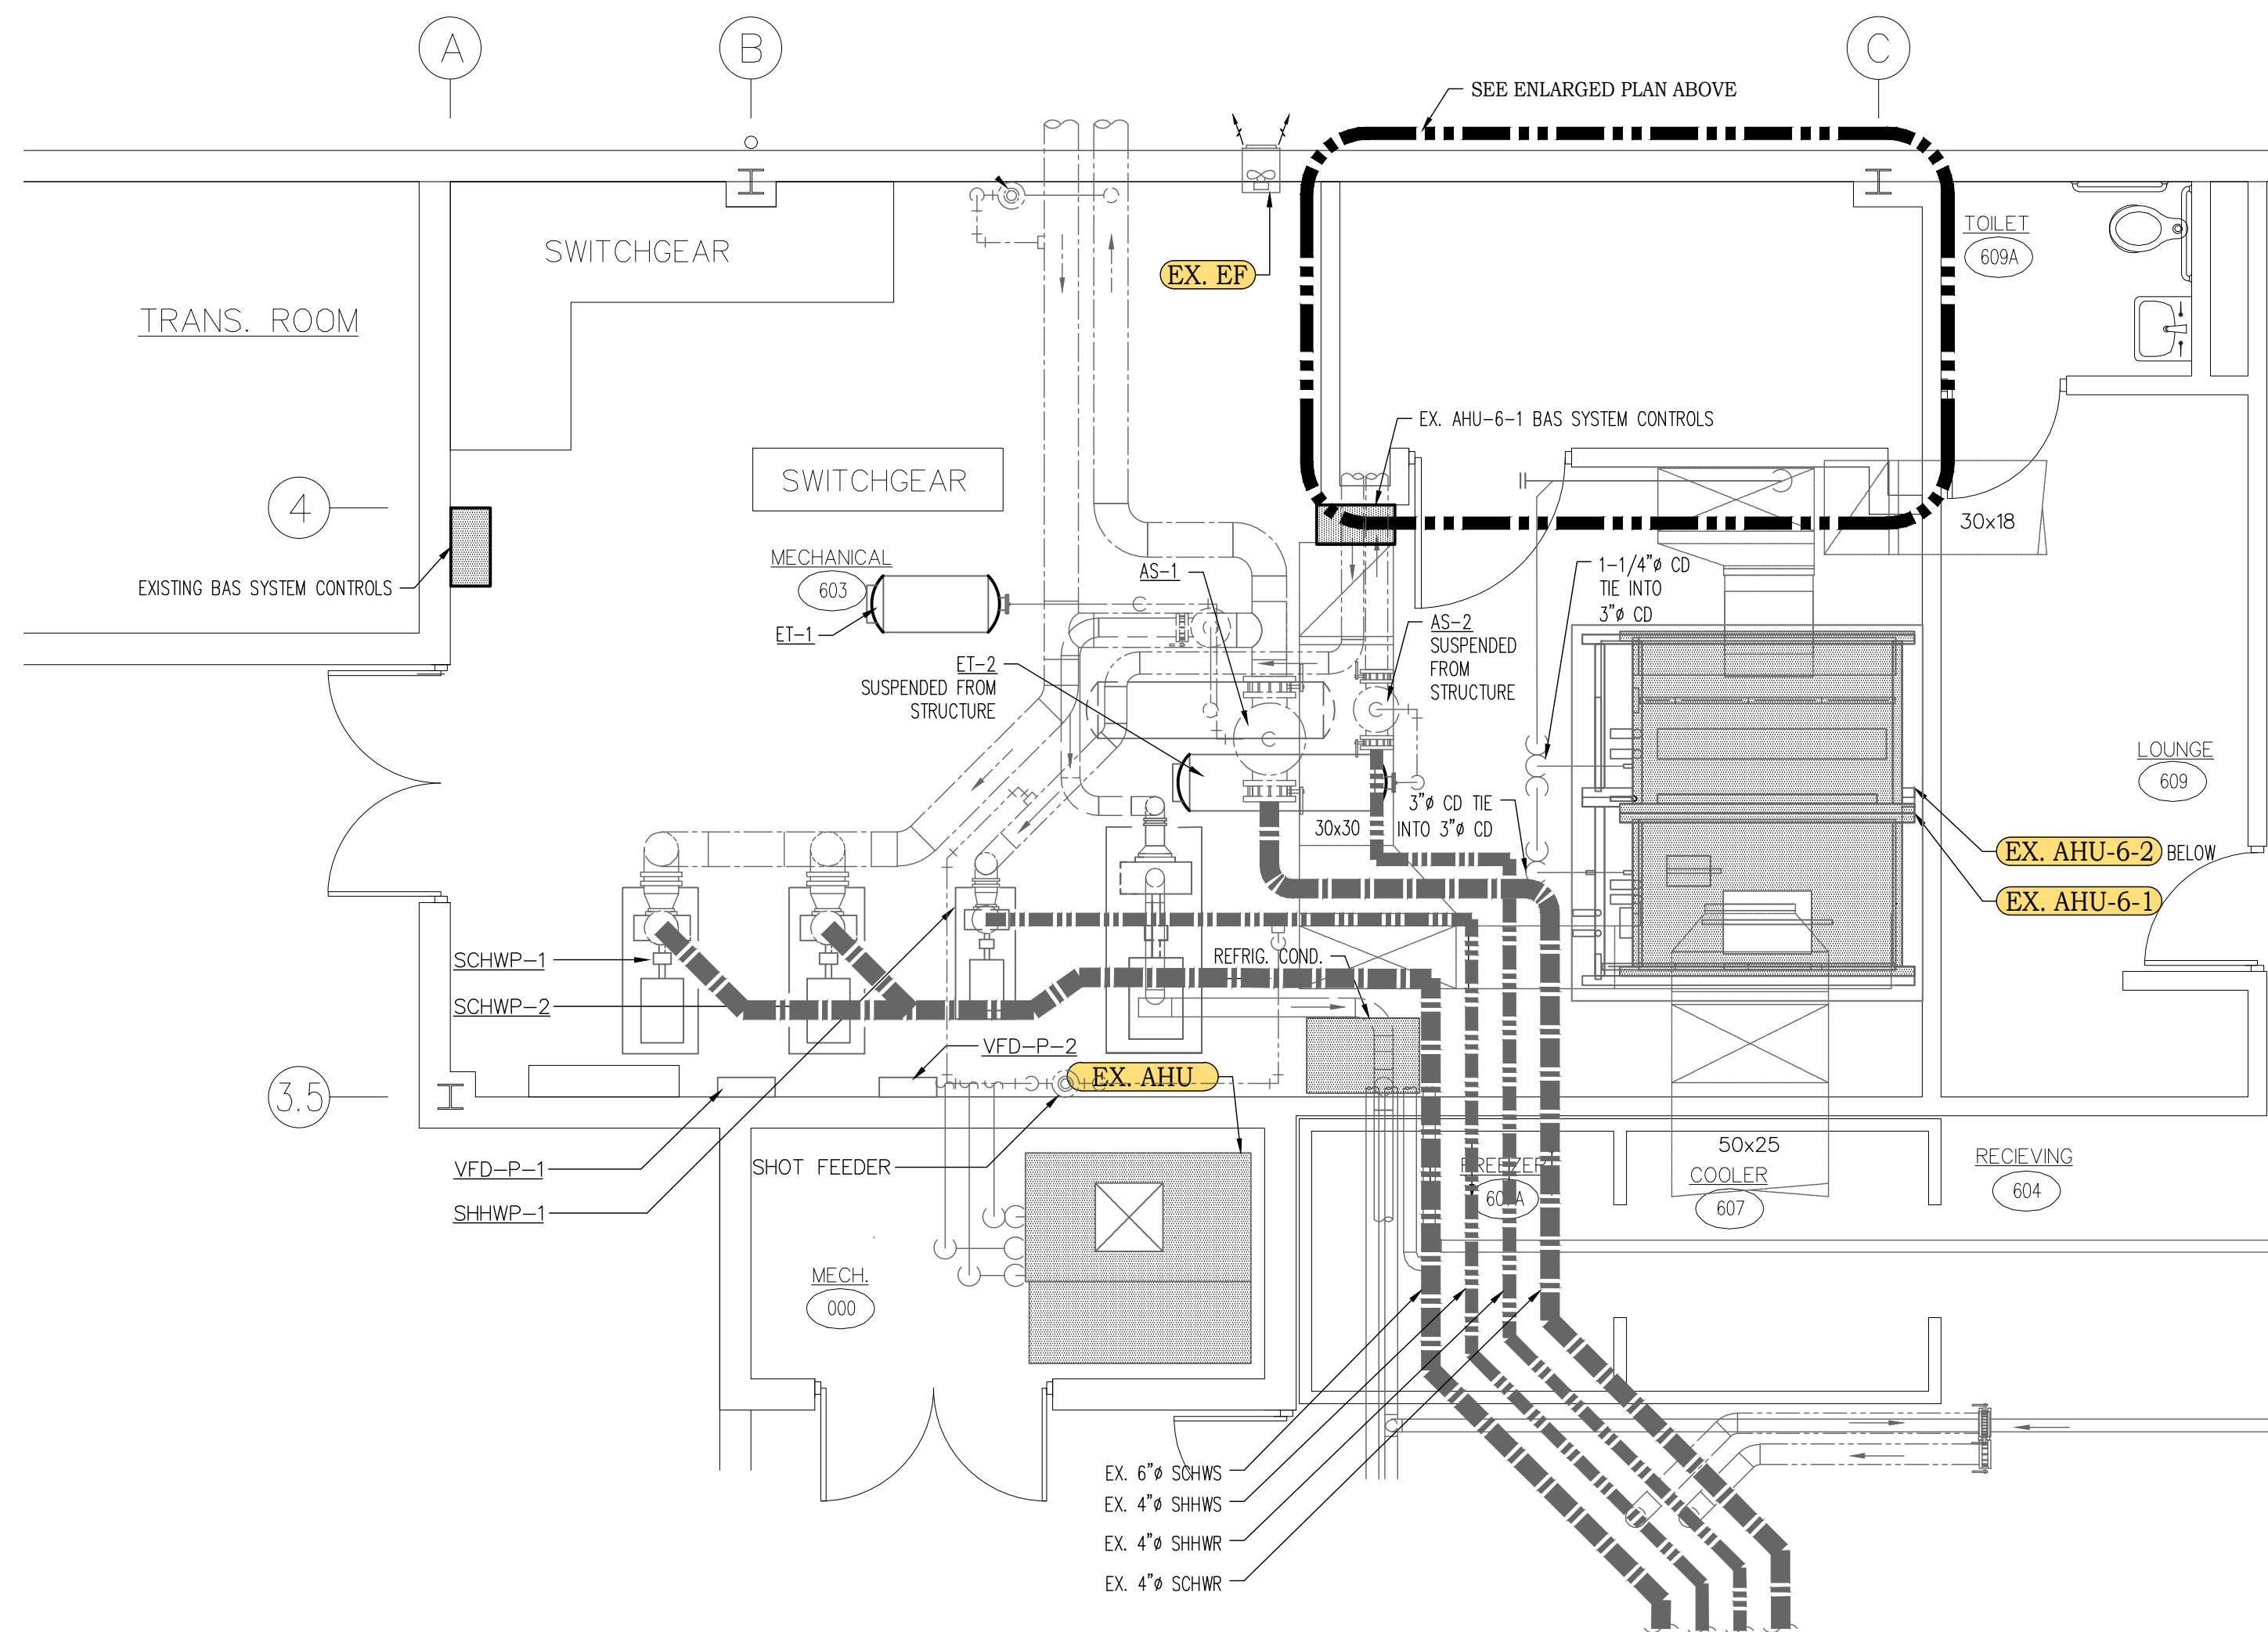

MECHANICAL PLAN
1/4" = 1'-0"

PLAN NOTES

1. INSTALL NEW BOILERS ON EXISTING CONCRETE PAD.
2. MODIFY PAD AS NECESSARY FOR NEW BOILERS.
3. CONNECT NEW BOILER TO EXISTING PIPING.
4. PROPERLY INSULATE ALL PIPING WITH SIMILAR TYPE INSULATION.
5. LABEL ALL PIPING.
6. CONNECT BOILERS TO EXISTING VENT SYSTEM.
7. INSTALL NEW BUTTERFLY VALVES.
8. INSTALL NEW ENTERING AND LEAVING HOT WATER TEMPERATURE SENSORS IN PIPES FOR EACH BOILER.
9. EXISTING DDC CONTROL PANEL TO CONNECT TO NEW BOILER CONTROL PANEL.



4083 South U.S. Highway 1, Ste. 101
Rockledge, Florida 32955
Phone 321.633.4522 Fax 321.633.4528
www.ddc-engineers.com
dasilva.david@ddc-engineers.com
C.O.A.: 25988
DDC PROJECT NO.: 25007.01

David A. DaSilva
54739

THIS ITEM HAS BEEN DIGITALLY SIGNED AND SEALED BY DAVID A. DASILVA ON THE DATE ADJACENT TO THE SEAL. PRINTED COPIES OF THIS DOCUMENT ARE NOT CONSIDERED SIGNED AND SEALED AND THE SIGNATURE MUST BE FORGED ON ANY ELECTRONIC COPIES.

REVISIONS

DOCUMENT HISTORY
NO. DATE DESCRIPTION

**HOLLY HILL SCHOOL
REPLACE BOILER**
VCS Project NO. 2648219
1500 CENTER AVENUE,
HOLLY HILL, FL. 32117


ENGINEER OF RECORD
ENGINEER
DAVID A. DASILVA

DESIGNED BY
DAD
DRAWN BY
IO/HR


ISSUE DATE
03/27/2026
AE PROJECT NUMBER
25007.01

SHEET TITLE
**MECHANICAL
PLANS**

DRAWING NO.
M100

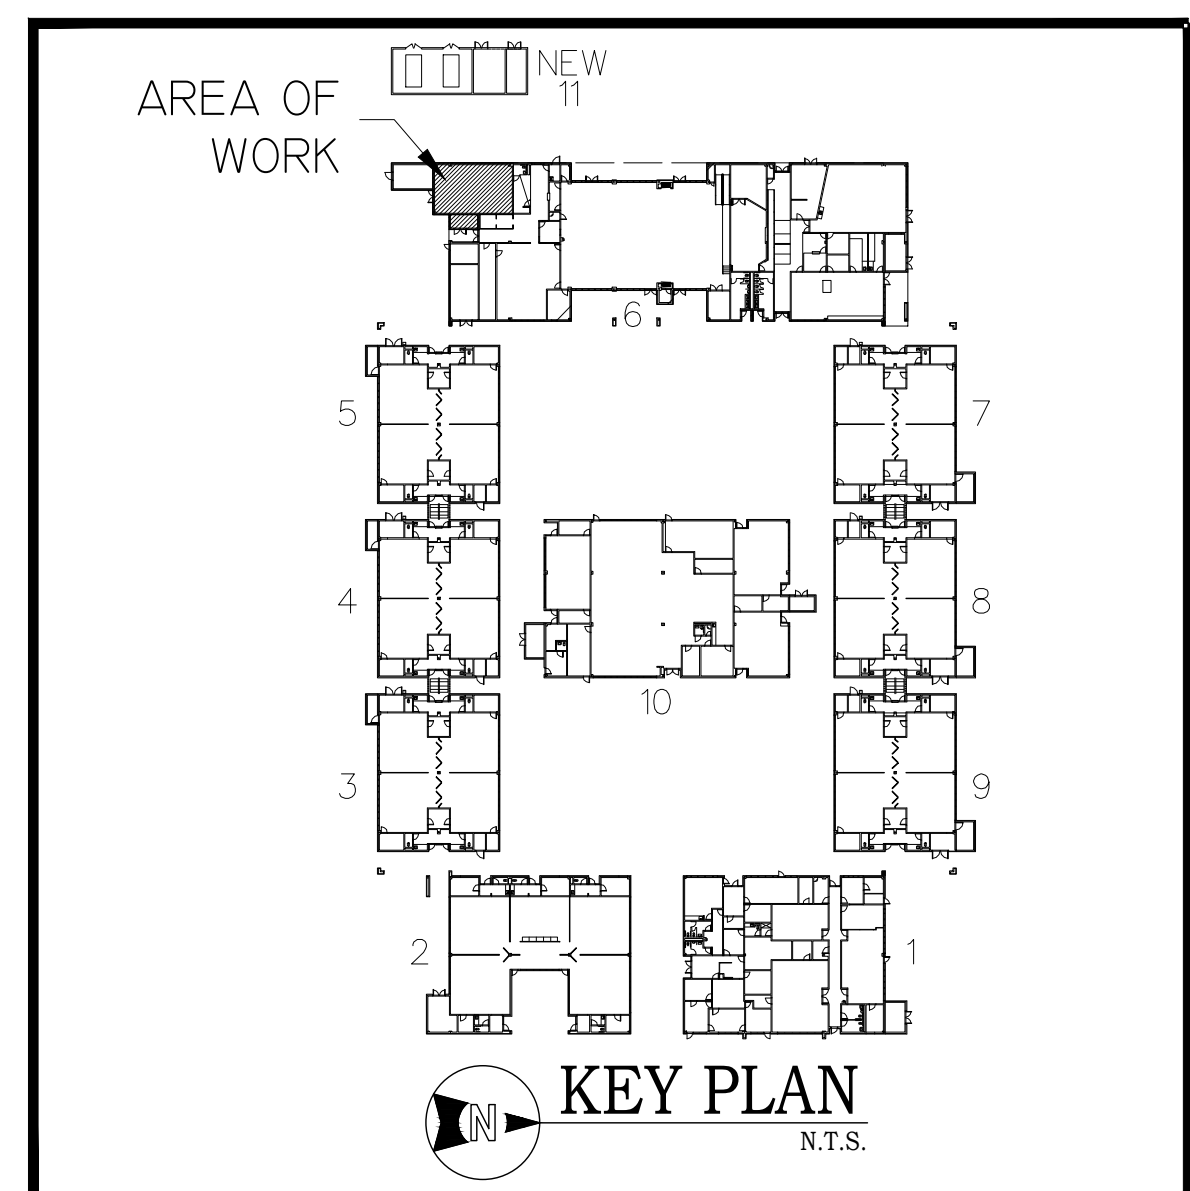

BOILER

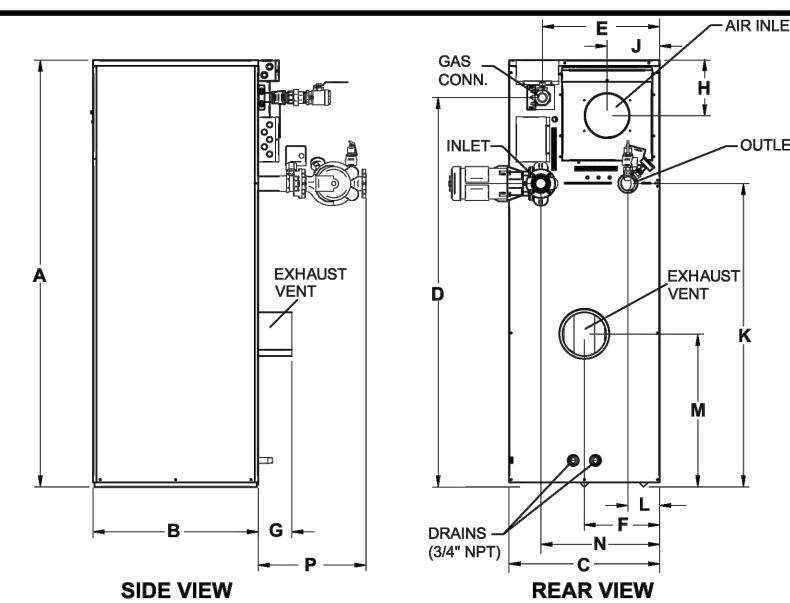


SIDE VIEW REAR VIEW

er Heater

Dimensions and Specifications

SIZES UP TO 3' SINGLE

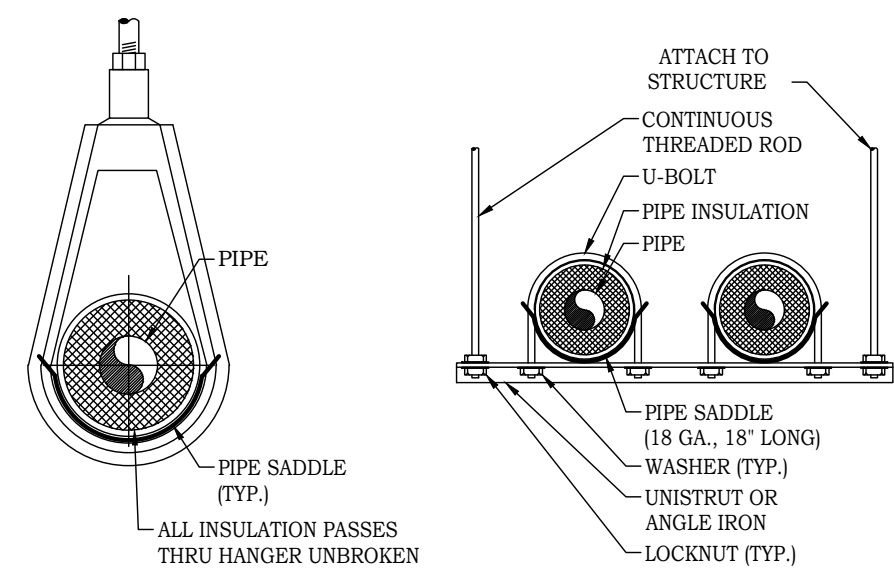


MULTIPLE

M1 INSULATED PIPE HANGER DETAIL

N.T.S.

M-D009

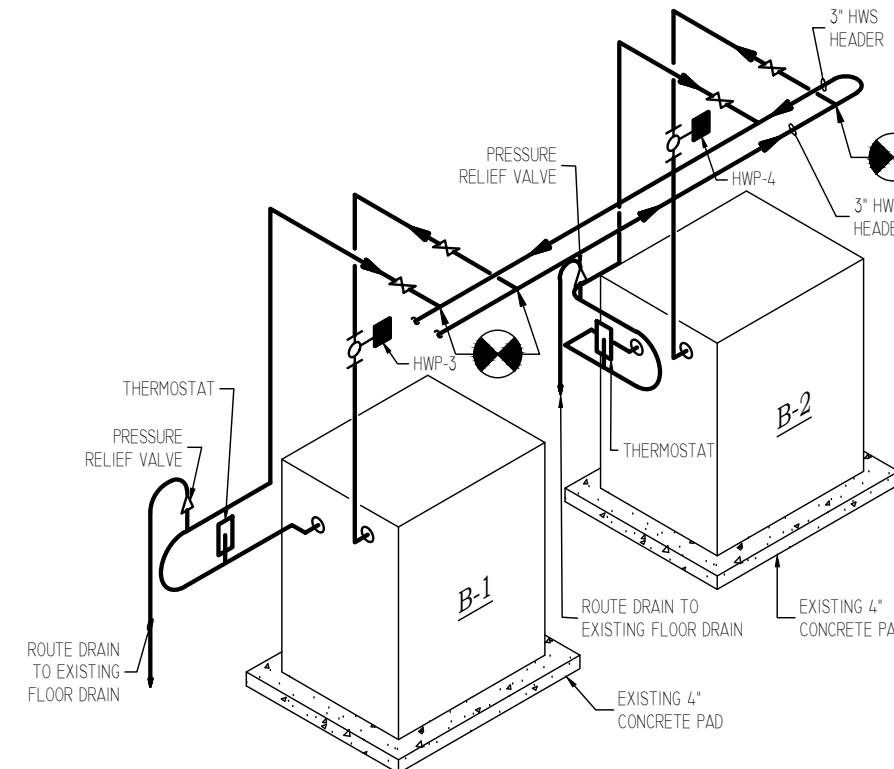


M2 HOT WATER BOILER DETAIL

N.T.S.

- NOTES:

1. BOILER CIRCUIT PIPING MUST BE SIZED LARGE ENOUGH TO HANDLE MAXIMUM FLOW THROUGH UNIT.
2. BOILER PUMP SIZED TO BOILER DESIGN FLOW REQUIREMENTS.
3. ALL BOILERS FURNISHED WITH FACTORY MOUNTED OUTLET WATER TEMPERATURE GAUGE.
4. BOILER PUMP PURGING REQUIRED. USE TERMINALS SUPPLIED.
5. A SENSOR IS REQUIRED AND INSTALLED AT A MINIMUM OF 12" FROM PRIMARY LOOP TEE.

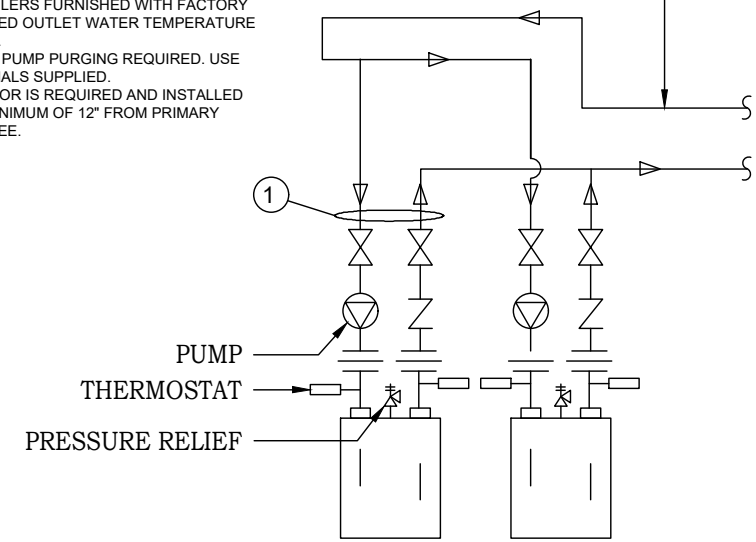

M3 MULTIPLE BOILERS DETAIL

4083 South U.S. Highway 1, Ste. 101
Rockledge, Florida 32955
Phone 321.633.4522 Fax 321.633.4528
www.ddc-engineers.com
dasilva.david@ddc-engineers.com
C.O.A.: 25988
DDC PROJECT NO.: 25007.01

David A. DaSilva
54739

THIS ITEM HAS BEEN DIGITALLY SIGNED AND SEALED BY DAVID A. DASILVA ON THE DATE ADJACENT TO THE SEAL. PRINTED COPIES OF THIS DOCUMENT ARE NOT CONSIDERED SIGNED AND SEALED AND THE SIGNATURE MUST BE VERIFIED ON ANY ELECTRONIC COPIES.

REVISIONS

DOCUMENT HISTORY

**HOLLY HILL SCHOOL
REPLACE BOILER
VCS Project NO. 26482
1500 CENTER AVENUE,
HOLLY HILL, FL. 32117**

ENGINEER
DAVID A. DASILVA

DESIGNED BY
DAD

DRAWN BY
IO/HF

ISSUE DATE

03/27/2026

AE PROJECT NUMBER
25007.01

SHEET TITLE

MECHANICAL DETAILS

DRAWING NO.

M500

NEW PUMP SCHEDULE

ITEM NO.		HWP-3	HWP-4
SERVICE		BOILER	BOILER
TYPE		INLINE	INLINE
WATER FLOW/PRESSURE DROP	GPM/PD	128 / 3.8	128 / 3.8
TOTAL DYNAMIC HEAD	FT/WTR.	15	15
MOTOR	HP	1.0	1.0
SPEED	RPM	1760	1760
EFFICIENCY	%	68	68
MOTOR TYPE		ODP	ODP
BASE TYPE		DRIP TYPE	DRIP TYPE
IMPELLER DIA.	IN.	5.5	5.5
SUCTION DIA.	IN.	2.5	2.5
DISCHARGE DIA.	IN.	2.5	2.5
ELECTRICAL	V/PH./HZ.	120/1/60	120/1/60
CONTROLS		EMS	EMS
WEIGHT	LBS.	---	---
LOCATION		BOILER ROOM	BOILER ROOM
MANUFACTURER		TACO	TACO
MODEL		19351-C	19351-C
NOTES		SEE BELOW	SEE BELOW

- PROVIDE ACCESSORIES:
- PUMP SHALL BE DELIVERED TO SITE WITH FULL SIZED IMPELLAR. IMPELLAR SHALL BE TRIMMED AFTER TEST & BALANCE CONFIRMS FLOW AND PRESSURE.
 - PUMPS SHALL BE ALTERNATED FOR USE BY THE DDC.
 - FLANGE CONNECTION - MOUNT VERTICAL.
 - PROVIDE PREMIUM EFF. MOTORS.
 - PROVIDE MOTOR STARTER/DISCONNECT.
 - PUMP IS PACKAGED WITH BOILER.
 - PUMP SIZING BASED ON HEAT EXCHANGER HEAD LOSS, 30 FEET OF PIPING AND SIX (6) 90° ELBOWS.


NEW BOILER SCHEDULE

ITEM NO.		B-1	B-2
SERVICE		HEATING	HEATING
OPERATING PRESSURE		160 PSIG	160 PSIG
STORAGE CAPACITY	GAL/L	5/18.93	5/18.93
WTR FLOW/PRESS DROP	GPM/FT	128/3.58	128/3.58
ENT/LVG TEMP	°F/°F	160/180	160/180
INPUT	BTU/H	1,500,000	1,500,000
OUTPUT	BUT/H	1,278,000	1,278,000
GAS BURNER		NATURAL	NATURAL
BLOWER	YES	YES	YES
BLOWER MOTOR	HP	1	1
FIRING RATE - OIL		---	---
FIRING RATE - GAS		1,500,000	1,500,000
HEATING SURFACE		COPPER	COPPER
WATER SIDE VOLUME	GAL	5	5
FIRE SIDE		---	---
ELECTRICAL	V/PH./HZ.	120/1/60	120/1/60
CONTOLS		-	-
OPERATING WEIGHT	LBS.	1,131	1,131
LOCATION		CENTRAL PLANT	CENTRAL PLANT
MANUFACTURER		LOCHINVAR	LOCHINVAR
MODEL		PFN-1501PM	PFN-1501PM
NOTES		SEE BELOW	SEE BELOW

- PROVIDE ACCESSORIES:
- CONTACTS FOR ANY FAILURE
 - LOW GAS PRESS. SWITCH
 - MANUAL RESET LOW WATER CUT OFF (LWCO)
 - BACNET CARD
- ACCEPTABLE MANUFACTURES: A.O. SMITH, CLEAVER BROOKS, RBI HEATNET FUTERA III 1500

- NOTE:
- CONTRACTOR TO REUSE EXISTING KMC CONTROLS AND MODIFY SYSTEM TO ACCOMMODATE NEW BOILERS AND GAS WATER HEATERS.
 - PROVIDE START/STOP OF ALL BOILERS AS WELL AS INDICATED PUMPS.
 - PROVIDE CURRENT SENSOR ON PUMPS.
 - PROVIDE WATER HEATER TEMPERATURE SENSOR ON INLET AND OUTLET OF BOILERS.

EXTENT OF NEW WORK

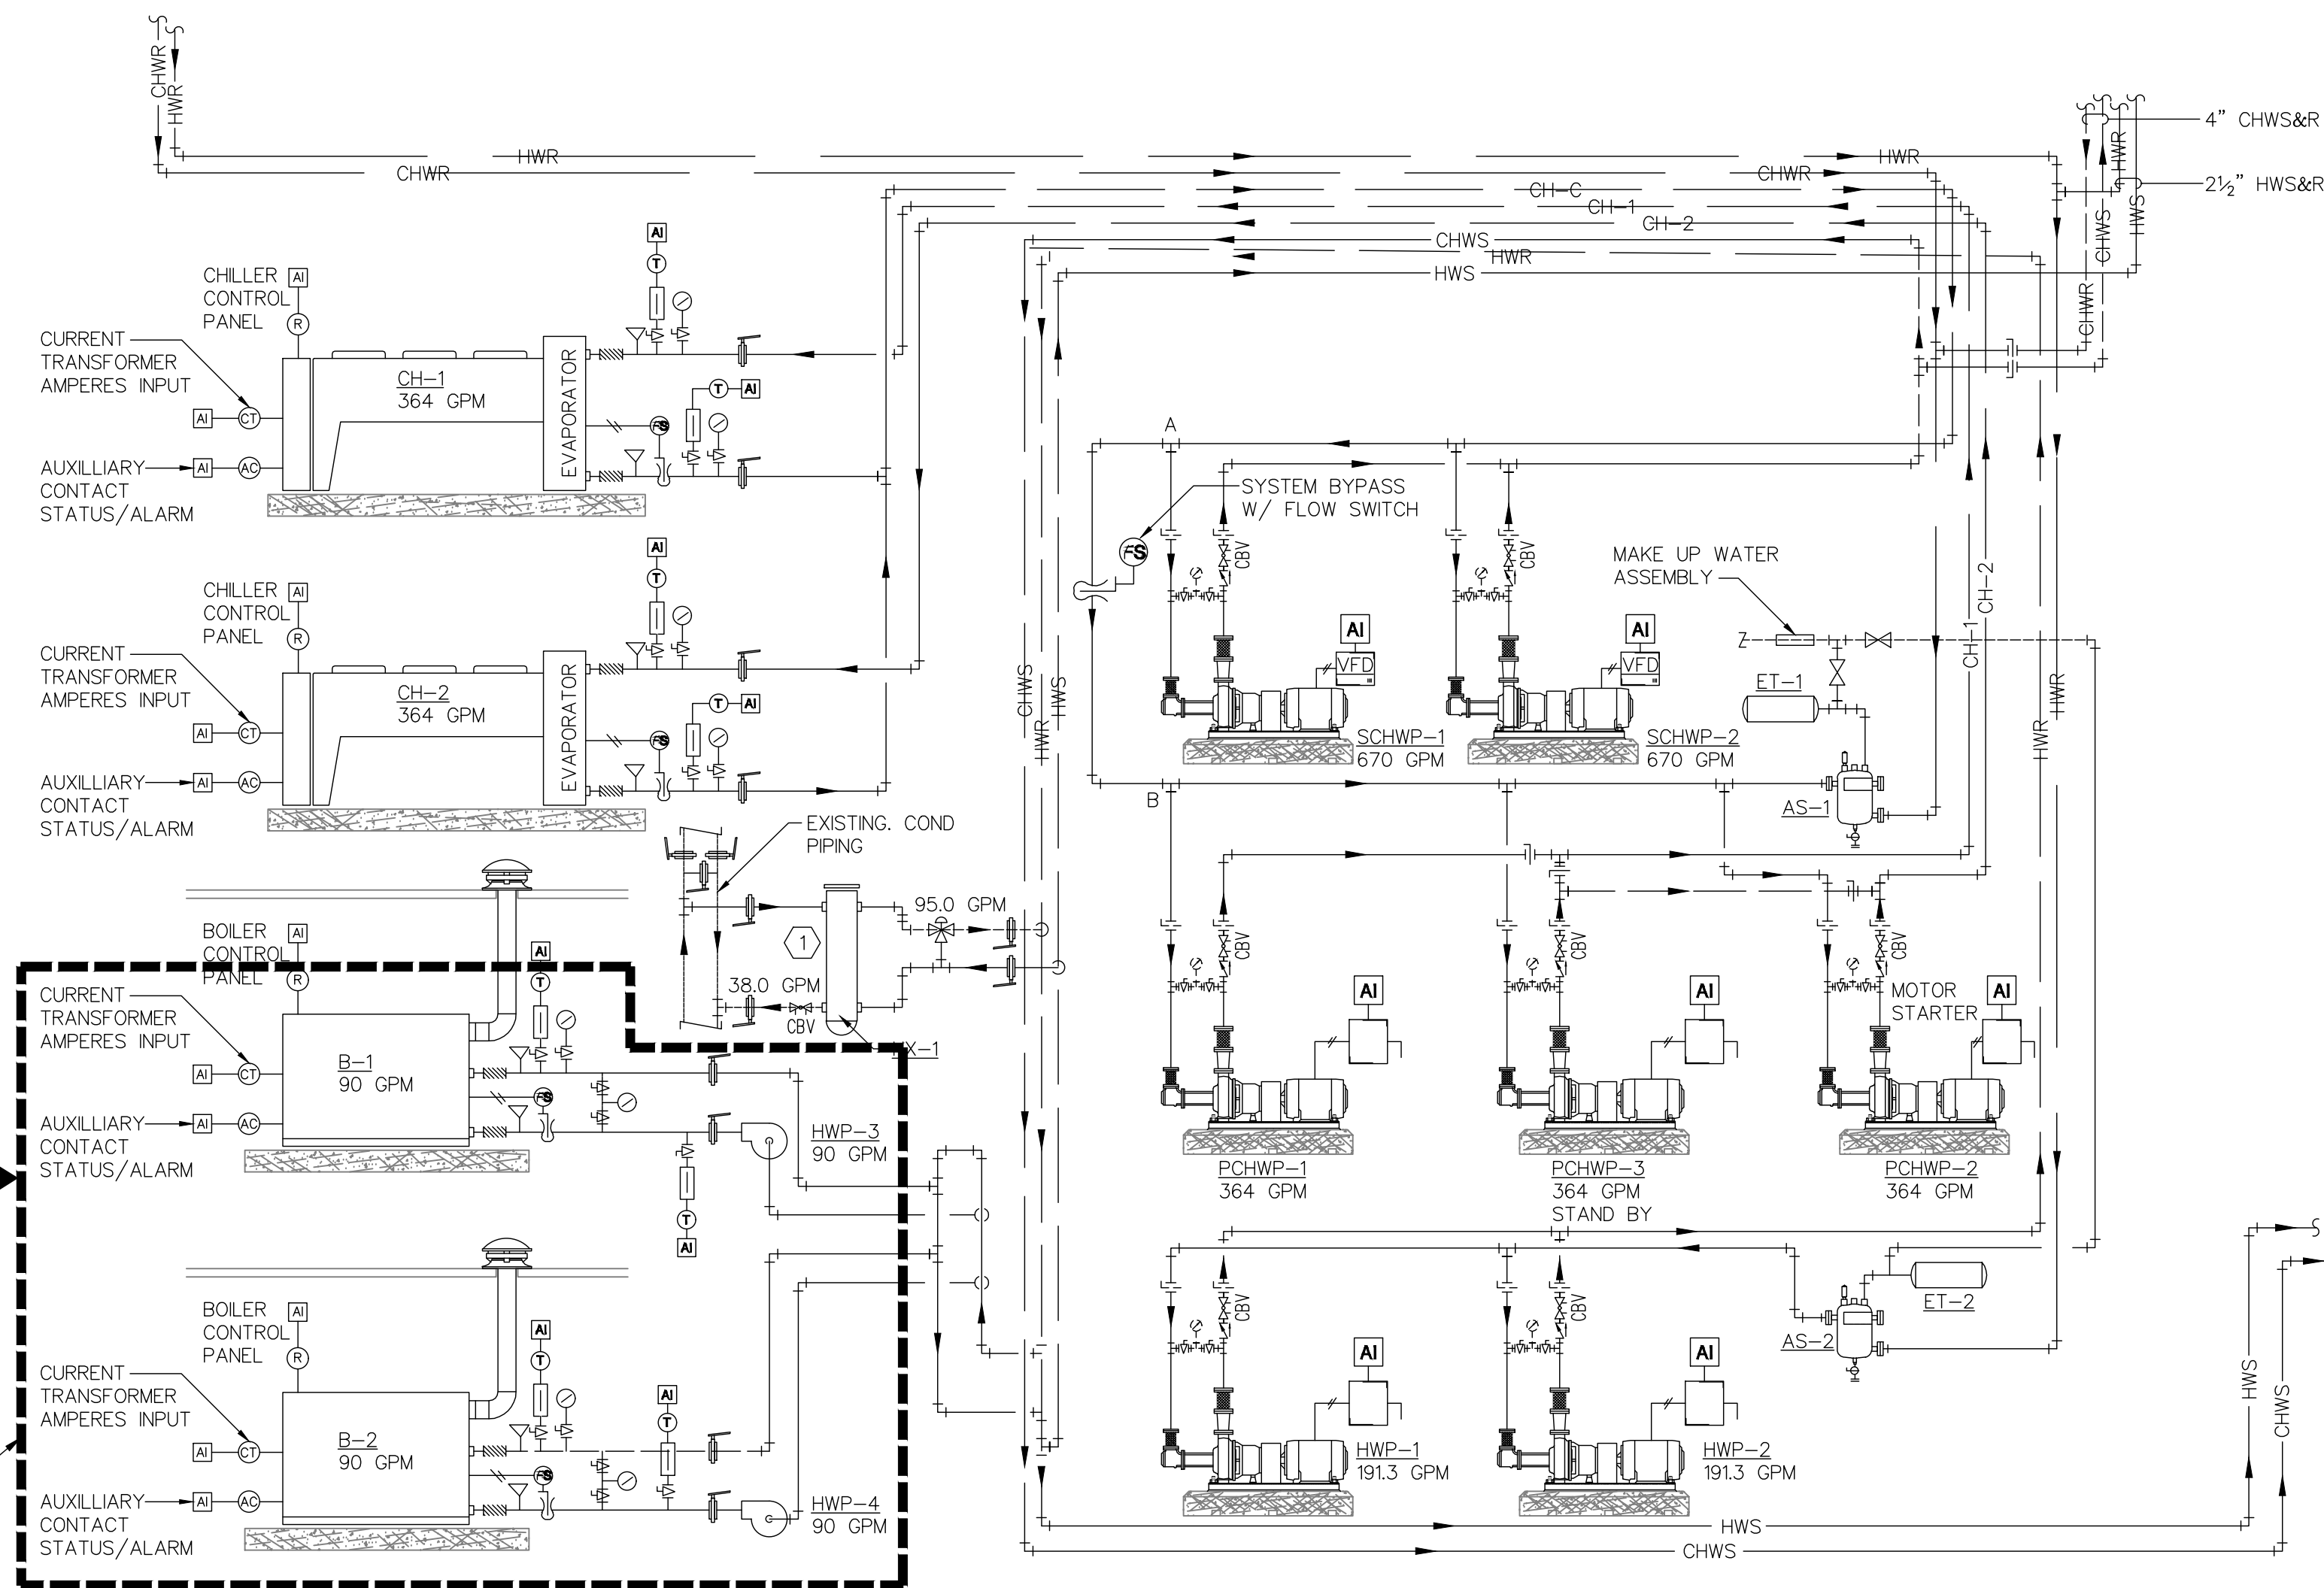

HVAC SCHEMATIC
N.T.S.



4083 South U.S. Highway 1, Ste. 101
Rockledge, Florida 32955
Phone 321.633.4522 Fax 321.633.4528
www.ddc-engineers.com
dasilva.david@ddc-engineers.com
C.O.A.: 25988
DDC PROJECT NO.: 25007.01

David A. DaSilva
54739

THIS ITEM HAS BEEN DIGITALLY SIGNED AND SEALED BY DAVID A. DASILVA ON THE DATE ADJACENT TO THE SEAL. PRINTED COPIES OF THIS DOCUMENT ARE NOT CONSIDERED SIGNED AND SEALED AND THE SIGNATURE MUST BE VERIFIED ON ANY ELECTRONIC COPIES.

REVISIONS

NO.	DATE	DESCRIPTION
-----	------	-------------

HOLLY HILL SCHOOL
REPLACE BOILER
VCS Project NO. 2648219
1500 CENTER AVENUE,
HOLLY HILL, FL. 32117

ENGINEER DAVID A. DASILVA	
DESIGNED BY DAD	DRAWN BY IO/HR
ISSUE DATE 03/27/2026	AE PROJECT NUMBER 25007.01
SHEET TITLE MECHANICAL SCHEDULES	
DRAWING NO. M600	

ELECTRICAL WORK, GENERAL SCOPE

PART 1 - GENERAL

 
 
 
 
 
 
 
 
 
- 1.01 DESCRIPTION
- A. DIVISION 16 OF THE SPECIFICATIONS COVERS ALL ELECTRICAL WORK FOR THE PROJECT. WORK SHALL INCLUDE LABOR, MATERIAL, AND ACCESSORIES NECESSARY TO ACCOMPLISH THE WORK AS SPECIFIED AND SHOWN ON THE DRAWINGS, INCLUDING CONNECTION AND CHECKOUTS OF EQUIPMENT FURNISHED BY OTHERS (OTHER TRADES, THE OWNER AND OTHER CONTRACTORS), AND TO ALL EQUIPMENT ITEMS AND AS INDICATED ON DRAWINGS OR AS REQUIRED.
- B. THE ARCHITECTURAL SPECIFICATIONS AND DRAWINGS INCLUDING THE GENERAL CONDITIONS, INCLUDING ALL SUPPLEMENTS ISSUED THERETO, INSTRUCTIONS TO BIDDERS, AND OTHER PERTINENT DOCUMENTS ISSUED BY THE ARCHITECT ARE A PART OF THESE SPECIFICATIONS AND ELECTRICAL DRAWINGS. THIS TRADE SHALL CONSULT THEM FOR INSTRUCTIONS WHICH APPLY TO HIM. DRAWINGS INDICATE THE GENERAL ARRANGEMENT OF THE ELECTRICAL LAYOUT AND WORK INCLUDED. THE ELECTRICAL WORK SHALL FOLLOW DRAWINGS IN LAYOUT THE ELECTRICAL WORK AND CONSULT THE DRAWINGS AND LAYOUTS OF OTHER TRADES TO VERIFY LOCATION AND SPACES IN WHICH WORK WILL BE INSTALLED.
- 1.02 CODES, PERMITS AND INSPECTION
- A. INSTALLATION SHALL COMPLY WITH THE 2020 NATIONAL ELECTRIC CODE, THE 2023 FLORIDA BUILDING CODE (8TH EDITION), AND THE MCPS FACILITY STANDARDS AND GUIDE SPECIFICATIONS.
- 1.03 QUALITY ASSURANCE
- A. THE FOLLOWING INDUSTRY STANDARDS AS APPLICABLE TO ELECTRICAL WORK, SHALL APPLY TO THE WORK OF THIS DIVISION EXCEPT THAT, WHERE THE REQUIREMENTS OF THESE SPECIFICATIONS ARE MORE THAN THE LISTED STANDARD, THESE SPECIFICATIONS SHALL TAKE PRECEDENCE.
- UL - UNDERWRITERS LABORATORIES
 - NEMA - NATIONAL ELECTRICAL MANUFACTURERS' ASSOCIATION
 - NECA - NATIONAL ELECTRICAL CONTRACTORS ASSOCIATION
 - ANSI - AMERICAN NATIONAL STANDARDS INSTITUTE
 - ASTM - AMERICAN SOCIETY OF TESTING MATERIALS.
- B. ALL MATERIALS SHALL BE NEW, UL LISTED AND LABELED WHERE LABELED MATERIALS ARE AVAILABLE, UN Damaged AND FREE OF DEFECTS AT TIME OF INSTALLATION. MATERIALS OR EQUIPMENT DAMAGED, IN SHIPMENT OR OTHERWISE DAMAGED PRIOR TO OR DURING INSTALLATION SHALL NOT BE REPAIRED AT THE JOB SITE, BUT SHALL BE REPLACED WITH NEW MATERIALS. WHEN THE MANUFACTURER'S NAME APPEARS IN THESE SPECIFICATIONS AND DRAWINGS, IT SHALL BE CONSTRUED THAT THE MANUFACTURER HAS TO MEET THE FULL REQUIREMENTS OF THE SPECIFICATIONS AND DRAWINGS AND THAT HIS STANDARD CATALOGED ITEM MAY BE UNACCEPTABLE WITHOUT MODIFICATION.
- 1.04 SUBMITTALS
- A. SHOP DRAWINGS AND PRODUCT DATA: SUBMIT SAME FOR EQUIPMENT AND/OR SYSTEMS AS INDICATED UNDER EACH SECTION OF THIS DIVISION. SHOP DRAWINGS SHALL INCLUDE SUFFICIENT INFORMATION TO INDICATE COMPLETE COMPLIANCE WITH SPECIFICATIONS.
- B. PRODUCT DATA: EACH CONTRACTOR SHALL ACCUMULATE DURING THE JOB PROGRESS THE FOLLOWING DATA IN DUPLICATE, PREPARED IN A NEAT BROCHURE OR POCKET FOLDER, AND TURNED OVER TO THE OWNER'S REPRESENTATIVE.
- ALL WARRANTIES, GUARANTEES AND MANUFACTURERS DIRECTIONS ON EQUIPMENT AND MATERIAL COVERED BY THE CONTRACT.
 - COPIES OF APPROVED SHOP DRAWINGS.
 - REPAIR PARTS LIST OF ALL MAJOR ITEMS AND EQUIPMENT INCLUDING NAME, ADDRESS AND TELEPHONE NUMBER OF LOCAL SUPPLIER OR AGENT.
- C. AT THE TIME OF EACH SUBMISSION, ANY DEVIATIONS FROM THE CONTRACT DOCUMENTS SHALL BE CALLED TO THE ATTENTION OF THE ARCHITECT-ENGINEER IN WRITING, AND SHALL BE PLAINLY MARKED ON THE SHOP DRAWINGS AND PRODUCT DATA.
- D. RECORD DRAWINGS: PROVIDE ONE COMPLETE SET OF CONTRACT DRAWINGS IN CLEAN, UN Damaged CONDITION, INDICATING ALL SIGNIFICANT CHANGES FROM THE WORK AS SHOWN. USE MULTIPLE PENCIL COLORS TO AID IN THE DISTINCTION BETWEEN WORK OF SEPARATE ELECTRICAL SYSTEMS. IN GENERAL, RECORD EVERY SUBSTANTIVE INSTALLATION OF ELECTRICAL WORK WHICH PREVIOUSLY IS EITHER NOT SHOWN, SHOWN INCOMPLETELY, OR FIELD MODIFIED.
- E. SHOW EXACT LOCATION OF UNDERGROUND CABLE AND CONDUITS INCLUDING HANDHOLES AND SIMILAR STRUCTURES, BOTH INTERIOR AND EXTERIOR, DRAWN TO SCALE AND FULLY DIMENSIONED FROM BUILDING COLUMN LINES.
- F. INDICATE MAINS AND BRANCHES OF WIRING SYSTEMS, WITH SWITCHGEAR, PANELBOARDS AND CONTROLS DEVICES LOCATED AND NUMBERED. LOCATE ALL DEVICES REQUIRING MAINTENANCE. INDICATE CHANGES IN EQUIPMENT RATINGS, SETTINGS, AND LOCATION. INDICATE SCOPE OF EACH CHANGE ORDER, NOTING CHANGE ORDER NUMBER.
- G. SUBMIT THE FOLLOWING UPON COMPLETION OF THE WORK: CERTIFICATE OF FINAL INSPECTION FROM LOCAL AUTHORITY, TABULATION OF ALL MOTORS LISTING RESPECTIVE MANUFACTURER, HORSEPOWER, NAMEPLATE VOLTAGE AND CURRENT, ACTUAL RUNNING CURRENT AFTER INSTALLATION AND OVERLOAD HEATER RATING.
- 1.05 OWNER RECORDS
- A. ACCUMULATE DURING THE PROGRESS OF THE JOB, THE FOLLOWING DATA IN DUPLICATE, AND PREPARE IN A NEAT BROCHURE OR PACKET FOLDER TO BE TURNED OVER TO THE OWNER AT SUBSTANTIAL COMPLETION: RECORD DRAWINGS PER ABOVE.
- B. ALL WARRANTIES, GUARANTEES, AND MANUFACTURER'S DIRECTION ON EQUIPMENT & MATERIAL FURNISHED.
- C. COMPLETE PLAIN ENGLISH STEP-BY-STEP OPERATING INSTRUCTIONS FOR THE ELECTRICAL SYSTEM. ONE COPY OF THESE INSTRUCTIONS SHALL BE FRAMED AND POSTED AS DIRECTED ON THE PREMISES.
- 1.06 MANUFACTURERS' NAMES AND CATALOG NUMBERS
- A. IN SOME INSTANCES, SPECIFIC REFERENCES HAVE BEEN MADE TO ONE OR MORE MANUFACTURERS' NAME AND MODEL OR USE NUMBERS AND CATALOG NUMBERS DOES NOT INDICATE THAT THE EQUIPMENT SPECIFIED IN NECESSARILY AN "OFF THE SHELF" ITEM. VARIANCES MAY BE DUE TO REQUIREMENT OF DESIRED FINISH, MATERIAL OR OTHER MODIFICATION.
- 1.07 PROTECTION OF EQUIPMENT
- A. ELECTRICAL EQUIPMENT SHALL BE PROTECTED FROM THE WEATHER, IN PARTICULAR, DRIPPING OR SPLASHING WATER, AT ALL TIMES DURING SHIPMENT, STORAGE AND CONSTRUCTION. MANUFACTURER'S RECOMMENDATIONS WITH REGARD TO STORAGE, PROTECTION, AND HANDLING SHALL BE FOLLOWED. SHOULD ANY APPARATUS BE SUBJECTED TO POSSIBLE INJURY DUE TO WATER, IT SHALL BE THOROUGHLY DRIED AND PUT THROUGH A DIELECTRIC TEST, AT THE EXPENSE OF THE CONTRACTOR, TO ASCERTAIN THE SUITABILITY OF THE APPARATUS OR IT SHALL BE REPLACED WITHOUT ADDITIONAL COST.
- C. DAMAGED OR DEFECTIVE EQUIPMENT: INSPECT ALL ELECTRICAL EQUIPMENT AND MATERIALS PRIOR TO INSTALLATION. INSTALLATION OR PLACEMENT INTO SERVICE OF DAMAGED MATERIALS WITHOUT THE PRIOR WRITTEN CONSENT OF THE OWNER IS PROHIBITED. REPAIR OR REPLACE OR REPAIR TO NEW EQUIPMENT, AS CERTIFIED BY THE MANUFACTURER, AND TEST DAMAGED EQUIPMENT IN COMPLIANCE WITH INDUSTRY STANDARDS AT NO ADDITIONAL COST TO THE OWNER. EQUIPMENT REQUIRED FOR THE TESTING SHALL BE PROVIDED BY THE CONTRACTOR.
- 1.08 WORKING CLEARANCE
- A. THE SIZE OF ELECTRICAL EQUIPMENT SHOWN ON THE DRAWINGS IS BASED ON DIMENSIONS OF A PARTICULAR MANUFACTURER (GENERALY THE FIRST NAMED), WHILE OTHER MANUFACTURERS MAY BE ACCEPTABLE, IT IS THE RESPONSIBILITY OF THE TRADE TO DETERMINE IF THE EQUIPMENT PROPOSED WILL FIT IN THE ALLOCATED SPACE.
- B. INSTALL ALL EQUIPMENT IN A MANNER TO PERMIT ACCESS TO ALL SURFACES. MAINTAIN PROPER CLEARANCE TO MEET ALL SAFETY AND OPERATING CODES, PARTICULARLY N.E. CODE. INSURE ALL REQUIREMENTS DICTATED BY OPERATION, CONTROL, ADJUSTMENT, MAINTENANCE AND POSSIBLE REPLACEMENT OF EQUIPMENT IN DETERMINING CLEARANCE.
- C. SHOULD THERE BE APPARENT VIOLATIONS OF N.E. CODE CLEARANCE, NOTIFY THE ARCHITECT-ENGINEER BEFORE PROCEEDING WITH CONNECTION OR PLACEMENT OF EQUIPMENT.
- PART 2 - PRODUCTS
- 2.01 GENERAL
- A. ALL EQUIPMENT OF A PARTICULAR KIND, SUCH AS SWITCHBOARDS, CONTROL CENTERS, PANELBOARDS, ETC., SHALL BE THE PRODUCT OF THE SAME MANUFACTURER.
- B. PROVIDE ACCESS PANELS FOR ALL EQUIPMENT AND DEVICES REQUIRING SAME. SIZE AS REQUIRED FOR PROPER ACCESS AND MAINTENANCE. MINIMUM ACCEPTABLE IS 12 IN. BY 12 IN. CLEAR OPENING WHERE HAND ACCESS ONLY IS REQUIRED.
- C. PROVIDE LABELS FOR EACH MOTOR CONTROLLER, SAFETY SWITCH, RELAY, PANELBOARD, CONTACTOR, TIMER, CONTROL DEVICE, METER AND CIRCUIT BREAKER. LABELS SHALL BE LAMINATED, PHENOLIC STRIPS 1/16 INCH THICK, AND ENGRAVED TO SHOW BLACK LETTERS ON A WHITE BACKGROUND NOT LESS THAN 1/4 INCH HIGH. SIZE STRIPS TO PROPERLY FIT MANUFACTURER'S BRACKETS AND BE LEGIBLE. WHERE MANUFACTURER'S BRACKETS ARE NOT PROVIDED, MOUNT LABELS WITH PROPER SCREWS, OR AN APPROVED ADHESIVE.
- D. PROVIDE MATCHING CIRCUIT BREAKERS FOR ALL EXISTING PANELBOARDS. UPDATE ALL PANEL DIRECTORIES.
- 2.02 RACEWAYS
- A. CONDUIT, RIGID STEEL, GALVANIZED AND MANUFACTURED IN ACCORDANCE WITH ANSI STANDARDS. FITTINGS SHALL BE PIPE THREADED, MALLEABLE IRON.
- B. CONDUIT, PVC, POLYVINYLCHLORIDE SCHEDULE 40 PIPE SPECIFICALLY MANUFACTURED AND LABELLED (UL STANDARD 651) FOR USE AS ELECTRICAL CONDUIT. FITTINGS SHALL BE EITHER SOCKET WELDED TYPE OR THREADED.
- C. CONDUIT, FLEXIBLE METALLIC: GALVANIZED, INTERLOCKED SPIRALLY WOUND STEEL STRIP WITH GALVANIZED OR SHERADIZED FITTINGS. LISTED PER UL-L. LIQUIDTIGHT FLEXIBLE METALLIC: GALVANIZED, INTERLOCKED SPIRALLY WOUND STEEL STRIP WITH OVERALL JACKET OF LIQUID TIGHT PVC, UL LISTED. FITTINGS SHALL BE STEEL OR MALLEABLE IRON WATER TIGHT.
- D. ELECTRIC METALLIC TUBING: GALVANIZED OR SHERADIZED AND MANUFACTURED IN ACCORDANCE WITH ANSI STANDARD C80.3. FITTINGS 3/4 INCH THROUGH 2 INCH TRADE SIZE SHALL BE COMPRESSION TYPE, MANUFACTURED FROM MALLEABLE IRON OR STEEL, AND RAIN AND/OR CONCRETE-TIGHT AS REQUIRED BY INSTALLATION. POT METAL OR DIE CAST TYPE FITTINGS ARE PROHIBITED. ONLY COMPRESSION FITTINGS TO BE USED IN INTERIOR SPACES.
- E. PROVIDE TYTON SURFACE MOUNTED RACEWAYS AS INDICATED IN DRAWINGS, AND IN ACCORDANCE WITH THE MCPS FACILITY STANDARDS.
- 2.03 CONDUCTORS AND CABLE
- A. GENERAL: ALL CONDUCTORS SHALL BE NINETY-EIGHT PERCENT (98%) CONDUCTIVITY SOFTDRAWN COPPER, NEW, INSULATED IN ACCORDANCE WITH N.E. CODE FOR THE TYPE OF SERVICE, UNLESS OTHERWISE NOTED. ALL ELECTRICAL CONDUCTORS SHALL BE INSULATED WITH TYPE THWV INSULATION AND HAVE STRANDED CONDUCTORS.
- B. CONNECTORS FOR SPLICING CONDUCTORS AWG AND SMALLER SHALL BE LIVE SPRING TYPE PRESSURE CONNECTORS AS MANUFACTURED BY 3M "SCOTCHLOK" OR APPROVED EQUAL.
- C. CONNECTORS FOR #6 AWG AND LARGER SHALL BE TWO-WAY LONG BARREL COMPRESSION TYPE WITH INSULATING COVER, THOMAS & BETTS "COLOR-KEYED" OR APPROVED EQUAL. WHERE "GUTTER TAPS" ARE REQUIRED CONNECTORS ARE TO BE H-TYPE WITH INSULATING COVERS.
- D. PROVIDE CAT-6E CABLE, JACKS, AND ACCESSORIES IN ACCORDANCE WITH THE MCPS FACILITY STANDARDS.
- 2.04 BOXES

- A. OUTLET BOXES: GALVANIZED PRESSED STEEL WITH GALVANIZED STEEL EXTENSION RINGS OR PLASTER RINGS OR TILE RINGS TO PROVIDE EXPOSED SURFACE FLUSH WITH WALL OR CEILING FINISH. PROVIDE ALL CEILING OUTLET BOXES WITH "NO-BOLT" OR THROUGH AND LOCKNUTTED TYPE FIXTURE STUDS. WELDED JUNCTION BOXES HAVE BEEN APPROVED, IN LIEU OF STAMPED BOXES.
- B. JUNCTION AND PULL BOXES: FABRICATE IN ACCORDANCE WITH NEMA AND N.E. CODE STANDARDS AND REQUIREMENTS INSOPAR AS MATERIAL, GAUGES, DIMENSIONS, AND FABRICATION METHODS. BOXES SHALL BEAR THE UL LABEL. WHERE BOXES ARE NOT SIZED ON THE DRAWINGS, THEY SHALL BE SIZED IN ACCORDANCE WITH N.E. CODE REQUIREMENTS. FINISH IN STANDARD GRAY ENAMEL, WITH SIDES AND BACK SPOT PAINTED. SLEEVES IN CONCRETE AND MASONRY WALLS, SHALL BE FABRICATED FROM STANDARD GALVANIZED STEEL PIPE WITH ENDS FINISHED SMOOTH, BURR FREE, WITHOUT SHARP EDGES.
- 2.05 PANELBOARDS
- A. FURNISH AND INSTALL SQUARE-D, GE, CUTTLER HAMMER, OR APPROVED EQUAL PANELBOARD DISTRIBUTION. PROVIDE TIN-PLATED COPPER BUS AND NEMA 1 ENCLOSURE (INDOOR), NEMA 3R (OUTDOOR). PROVIDE BOLT-ON MOLDED CASE CIRCUIT BREAKERS AS REQUIRED TO MATCH EXISTING. ALL PANELS SHALL BE UL LISTED.
- PART 3 - EXECUTION
- 3.01 METHOD OF PROCEDURE
- A. ERECT EQUIPMENT PARTS AT SUCH TIME AND IN SUCH MANNER AS TO MINIMIZE INTERFERENCES AND DELAYS IN THE EXECUTION OF THE WORK CARE SHALL BE USED IN THE ERECTION AND INSTALLATION OF ALL EQUIPMENT AND MATERIALS TO AVOID MARRING SURFACES OF THE WORK. DAMAGES SHALL BE REPAIRED AT NO ADDITION COST TO THE OWNER.
- B. PROVIDE OPENINGS THROUGH WALLS, PARTITIONS, FLOORS, AND ROOFS AS REQUIRED FOR ELECTRICAL WORK, THROUGH FLOORS, WALLS AND PARTITIONS AND SHALL BE CUT FLUSH WITH EACH SURFACE UNLESS OTHERWISE SPECIFIED. FIRE WALL AND/OR FLOOR INTEGRITY SHALL BE RESTORED AFTER PENETRATION. SLEEVES IN CONCRETE AND MASONRY WALLS, SHALL BE FABRICATED FROM STANDARD GALVANIZED STEEL PIPE WITH ENDS FINISHED SMOOTH, BURR FREE, WITHOUT SHARP EDGES.
- 3.02 RACEWAYS
- A. GENERAL: ALL POWER AND LIGHTING CIRCUITS SHALL BE RUN IN CONCEALED METALLIC RACEWAYS EXCEPT WHERE SPECIFICALLY NOTED OTHERWISE. THESE RACEWAYS SHALL BE RUN CONCEALED IN ALL FINISHED AREAS, AND WHERE RUN EXPOSED SHALL BE SQUARE TO THE BUILDING AND HELD TIGHT TO THE BUILDING CONSTRUCTION. THE POINTS OF TERMINATION AND THE SUGGESTED ROUTING. HOWEVER, THE INSTALLER IS RESPONSIBLE FOR PROPER COORDINATION WITH BUILDING STRUCTURE AND THE WORK OF OTHER TRADES. FURNISH ALL REQUIRED ELBOWS, FITTINGS, JUNCTION AND PULL BOXES, WHETHER OR NOT SPECIFICALLY SHOWN ON DRAWINGS, THAT MAY BE REQUIRED TO SATISFY CODES AND THE STANDARDS OF GOOD PRACTICE. WHERE CONDUITS FOR BOTH BRANCH AND FEEDER CIRCUITS ARE RUN CONCEALED, THEY MAY BE RUN OUT OF SQUARE TO THE BUILDING PROVIDING THE SHORTEST POSSIBLE RUN IS MAINTAINED. RACEWAY SIZES ARE BASED ON THE USE OF COPPER CONDUCTORS AND N.E. CODE FILL.
- B. GRS CONDUIT SHALL BE CUT WITH POWER OR HACKSAW AND CLEANLY REAMED TO REMOVE ALL "BURRS" AND ALL FIELD CUT THREADS SHALL BE PAINTED WITH WHITE LEAD BEFORE COUPLINGS ARE APPLIED.
- C. WHERE BUILDING VENTILATION CONDITIONS ARE SUCH THAT AIR MAY FLOW CONTINUOUSLY IN CONDUITS, CAUSING CONDENSATION AND THE COLLECTION OF MOISTURE, THE CONDUITS SHALL BE COATED AT EACH END WITH A PROTECT SEALING COMPOUND. ALSO SEAL ALL CONDUIT ENTERING AND LEAVING REFRIGERATED EQUIPMENT.
- 3.03 WIRING INSTALLATION
- A. GENERAL: EXCEPT FOR SUCH ITEMS AS ARE NORMALLY WIRED AT THEIR POINT OF MANUFACTURE AND SO DELIVERED - AND UNLESS SPECIFICALLY NOTED TO THE CONTRARY HEREIN - THE ELECTRICAL TRADE SHALL DO ALL ELECTRICAL WIRING OF EVERY CHARACTER. IT IS THE INTENT OF THESE SPECIFICATIONS AND DRAWINGS THAT ALL SYSTEMS AND EQUIPMENT SHALL BE PROVIDED WITH ALL NECESSARY UTILITY CONNECTIONS, COMPLETED TO ALLOW SAFE AND PROPER OPERATION OF SAID SYSTEMS. WHEN IT IS NECESSARY FOR TRADES PERFORMING WORK COVERED BY THIS DIVISION TO MAKE FINAL CONNECTIONS TO ITEMS OF EQUIPMENT BEING FURNISHED BY OTHERS, OR BY OTHER TRADES UNDER OTHER DIVISIONS, ALL SUCH WORK SHALL BE PERFORMED IN ACCORDANCE WITH THE REQUIREMENTS OF THIS DIVISION AND ALL MATERIALS USED SHALL BE AS SPECIFIED HEREIN.
- B. WIRE SIZE: MINIMUM WIRE SIZE FOR BRANCH CIRCUITS SHALL BE #12 AWG.
- C. MAKE CONNECTIONS TO TERMINALS USING PRESSURE-TYPE CONNECTORS. SOLDERED JOINTS ARE PROHIBITED. ALL JOINTS IN CONDUITS SHALL BE MADE AT AN ACCESSIBLE LOCATION WITHIN A BOX BY TWISTING THE BARE CONDUCTOR ENDS TOGETHER AND APPLYING A WIRE CONNECTOR IN ALL SIZES UP TO THE MAXIMUM CAPACITY OF THE CONNECTOR. JOINTS SHALL BE TAPED WITH AN APPROVED ELECTRICAL TAPE. SPLICERS LARGER THAN #10 AWG SHALL BE MADE WITH AN APPROVED APPROVED COMPRESSION (SQUEEZE) CONNECTOR INSULATED WITH NOT LESS THAN TWO LAYERS OF ELECTRICAL FILL TAPE TO 1.5 TIMES THE THICKNESS OF INSULATION, FOLLOWED BY TWO (MINIMUM) LAYERS OF HALF-LAPPED ELECTRICAL TAPE FOR MECHANICAL PROTECTION. LOCATE ALL SPLICES IN BOXES OR FITTINGS OF THE N.E. CODE.
- D. IDENTIFY ALL WIRES AND CABLES WITH BRADY ADHESIVE WIRE MARKERS AT EACH BOX, PANEL, AND OUTLET. IDENTIFICATION SHALL, AS A MINIMUM, INDICATE THE PANEL AND CIRCUIT SUPPLYING THE OUTLET. AT THE PANEL END, THE WIRE SHALL BE IDENTIFIED AND ITS LOCATION SHALL BE INDICATED. PROVIDE A MINIMUM OF 8 IN. SLEEVE WIRE AT EACH OUTLET FOR MAKING CONNECTION TO THE DEVICE OR TO PROVIDE FOR A FUTURE DEVICE IN THE BOX.
- 3.04 SYSTEM GROUNDING
- A. GENERAL: EQUIPMENT, RACEWAY SYSTEMS, WIRING SYSTEM NEUTRALS, RECEPTACLES AND POWER OUTLETS, MOTORS AND MOTORIZED EQUIPMENT, SHALL BE GROUNDED IN ACCORDANCE WITH NEC ARTICLE 250.
- B. GROUNDED RECEPTACLES AND POWER OUTLETS TO THE CONDUIT SYSTEM WITH A GREEN GROUNDING CONDUCTOR SIZE IN ACCORDANCE WITH NEC TABLE 250 AND CONNECTED BETWEEN THE DEVICE GROUNDING SCREW AND THE OUTLET BOX. CONNECTION TO THE BOX MAY BE A "G" CLIP OR BY A 10/24 SCREW THREADED INTO A HOLE IN THE BACK OF THE BOX AND USED FOR NO OTHER PURPOSE. BONDING JUMPER REQUIREMENTS MAY BE WAIVED, SUBJECT TO THE APPROVAL OF THE N.E. CODE REQUIREMENTS ENFORCING AUTHORITY. PROVIDED THE RECEPTACLE USED IS OF THE SAFETY GROUNDING TYPE LISTED BY UL AS COMPLYING WITH EXCEPTION NO. 2 OF N.E. CODE ARTICLE 250-74. EQUIPMENT CONNECTED TO THE ELECTRICAL SYSTEM SHALL BE GROUNDED WITH INSULATED GREEN GROUNDING CONDUCTOR SIZED IN ACCORDANCE WITH N.E. CODE TABLE 250-95 AND INSTALLED WITHIN THE RACEWAY. CONDUCTOR SHALL BE CONTINUOUS BETWEEN A GROUNDING SCREW IN THE EQUIPMENT JUNCTION BOX AND A GROUND ATTACHMENT IN THE NEAREST OUTLET BOX IN THE RIGID METALLIC CONDUIT SYSTEM. THIS REQUIREMENT INCLUDES ALL FLEXIBLE CONDUIT.
- C. GROUNDING MATERIAL:
- GROUND CONDUCTOR - SIZE AS PER NEC REQUIREMENTS, THHN, SOFT DRAWN OR SOFT ANNEALED, COPPER WIRE
 - JOINTS AND CONNECTIONS - MOLDED FUSION WELDING PROCESS USING PROPER MOLD AND THE NUMBER, SIZE AND TYPE CARTRIDGE FOR THE JOINT OR CONNECTION. WATERPROOF CONNECTION. SILICON BRONZE APPROVED MECHANICAL CONNECTOR DESIGNED FOR THE PIPE AND CABLE TO BE BONDED.
- 3.05 PANELBOARD INSTALLATION
- A. DIRECTORIES, AS A MINIMUM, SHALL BE TYPEWRITTEN AND INDICATE BREAKER POSITION NUMBER, EQUIPMENT SERVED, ROOM NAME AND NUMBER, AND THE PANEL IDENTIFICATION.
- B. NO WATER PIPING SHALL BE ABOVE SWITCHBOARD, MCC, OR PANELS.
- C. MOUNT PANELBOARDS WITH CENTERLINE AT 5 FT.-6IN. ABOVE FINISH FLOOR, EXCEPT THAT THE HIGHEST BREAKER HANDLE SHALL BE BELOW 6 FT. - 5 IN. ABOVE FINISH FLOOR. ARRANGE BREAKERS SO THAT THE BREAKER RATING IS VISIBLE WITH THE PANEL FRONT IN PLACE.
- 3.06 CLEANING
- A. THOROUGHLY CLEAN ALL PANELBOARDS, AND EQUIPMENT PROVIDED OR CONNECTED IN THIS CONTRACT. ALL SURFACES SHALL BE PROPERLY POLISHED AND SHALL BE FREE OF PAINT AND ALL OTHER DIRT OR DEBRIS. TOUCHUP OR COMPLETELY REFINISH ALL EQUIPMENT FURNISHED WITH FACTORY FINISHES THAT IS DAMAGED DURING DELIVERY OR CONSTRUCTION. PROPERLY PROTECT THE FRONTS OF ALL PANELBOARDS, SWITCHBOARDS AND SIMILAR EQUIPMENT TO PREVENT MARRING AND OTHER DEPAFING.
- B. AT ALL TIMES, KEEP THE PREMISES FREE FROM ACCUMULATIONS OF WASTE MATERIALS OR RUBBISH CAUSED BY THE WORK OF THE TRADESMEN DOING ELECTRICAL WORK. AT COMPLETION OF THE WORK, REMOVE ALL RUBBISH, TOOLS, EQUIPMENT, AND SURPLUS MATERIALS. BROOM CLEAN ALL ASSIGNED SPACES PRIOR TO LEAVING THE PREMISES.
- END OF SECTION

GENERAL NOTES:

- ALL ELECTRICAL WORK SHALL BE DONE ACCORDING TO THE 2014 EDITION OF THE NATIONAL ELECTRICAL CODE, THE 2023 FLORIDA BUILDING CODE, AND THE SBBC FACILITIES FACILITIES STANDARDS AND GUIDE SPECIFICATIONS.
- ALL ELECTRICAL CONDUITS SHALL CARRY A GREEN INSULATED COPPER WIRE SIZED PER NEC UNLESS OTHERWISE INDICATED ON THE DRAWINGS. GROUND ELECTRICAL DISTRIBUTION SYSTEM IN ACCORDANCE WITH THE 2014 EDITION OF THE NEC.
- FEEDER CONDUCTORS AND CONDUIT SIZES ARE INDICATED ON DIAGRAMS & SCHEDULES.
- ALL WORK MUST BE IN CONFORMANCE WITH THE VOLUSIA COUNTY SCHOOL (VCS) STANDARDS.
- CONTRACTOR SHALL RELOCATE EXISTING DEVICES AS REQUIRED TO ACCOMMODATE NEW HVAC EQUIPMENT. EXTEND CONDUITS AND WIRING AS REQUIRED.

ELECTRICAL SYMBOLS LEGEND

		ABBREVIATIONS
	J-BOX	A AMPERES
	HOME RUN	AC ALTERNATING CURRENT OR AIR CONDITIONER
	NON-FUSED DISCONNECT SWITCH	ADA AMERICANS W/ DISABILITIES ACT
	FUSED DISCONNECT SWITCH	APC ABOVE FINISHED COUNTER
	COMBINATION MOTOR STARTER/FUSED DISCONNECT SWITCH	AFF ABOVE FINISHED FLOOR
	BRANCH CIRCUIT PANELBOARD, UNDER 250 VOLTS, RECESSED MOUNTED	APG ABOVE FINISHED GRADE
	SURGE PROTECTION DEVICE (SPD)	AHU AIR HANDLING UNIT
	NEW COMM/DATA OUTLET WITH FLUSH MOUNTED 4" SQUARE SINGLE GANGE JUNCTION BOX MOUNTED ABOVE COUNTER UNLESS NOTED OTHERWISE. EXTEND 1" CONCEALED CONDUIT TO ABOVE ACCESSIBLE CEILING AND STOP-OUT WITH PLASTIC BUSHING OR AS NOTED. INSTALL PULL WIRE.	AIC AMPS INTERRUPTING CAPACITY
	PHOTOELECTRIC DUCT SMOKE DETECTOR, COMPLIANT WITH NFPA 90A: 6.4.4.2	AWG AMERICAN WIRE GAUGE
	R-RETURN S-SUPPLY	C CONDUIT
	FIRE ALARM SHUTDOWN RELAY	CATV CABLE TELEVISION
	DUCT DETECTOR REMOTE TROUBLE INDICATOR. MOUNT ADJACENT TO UNIT.	CH COUNTER HEIGHT
	COMBINATION AUDIBLE/VISUAL SIGNALING UNIT- HORN/FLASHING "FIRE" LIGHT WALL MOUNTED.	COND CONDUIT
	WP-WEATHER PROOF. A-AUDIBLE ONLY.	CU COPPER OR CONDENSER UNIT
	75 CANDELA MINIMUM.	DISC DISCONNECT
	FIRE ALARM HEAT DETECTOR.	ECB ENCLOSED CIRCUIT BREAKER
	CEILING MOUNTED FIRE ALARM SMOKE DETECTOR.	EF EXHAUST FAN
	SHEET NOTE CALLOUT	ELEC ELECTRICAL
	REVISION REFERENCE	EMS ENERGY MANAGEMENT SYSTEM
	WIRE CALLOUT	EMT ELECTRICAL METALLIC TUBING
	LIGHT DASHED INDICATES EXISTING FIXTURE OR DEVICE	ETR EXISTING TO REMAIN
	DARK DASHED INDICATES EXISTING FIXTURE OR DEVICE RELOCATED	EWC ELECTRIC WATER COOLER
	DARK SOLID INDICATES NEW FIXTURE OR DEVICE	EWX ELECTRIC WATER HEATER
	HATCHED ITEMS INDICATES FIXTURE OR DEVICE TO BE REMOVED OR RELOCATED	EX EXISTING
	NOT IN CONTRACT (N.I.C.)	EXIST EXISTING
	AUTOMATIC TRANSFER SWITCH	FA FIRE ALARM
	BRANCH CIRCUIT PANELBOARD, UNDER 250 VOLTS, SURFACE MOUNTED	FACP FIRE ALARM CONTROL PANEL

SHOP DRAWING SUBMITTALS

ITEM	COPY FOR OWNER REVIEW	PRODUCT DATA	SHOP DRAWINGS				TEST REPORTS	COORDINATION DRAWINGS		WIRING DIAGRAMS	O & M MANUAL	
			1	2	3	4	1	2	1	2	1	2
ELECTRICAL GEAR	×	×	×	×	×	×	×	×	×	×	×	×
GROUNDING DEVICES	×	×	×	×	×	×	×	×	×	×	×	×
CONDUIT/FITTINGS	×	×	×	×	×	×	×	×	×	×	×	×
FEEDERS	×	×	×	×	×	×	×	×	×	×	×	×
WIRING DEVICES	×	×	×	×	×	×	×	×	×	×	×	×
LIGHTING	×	×	×	×	×	×	×	×	×	×	×	×
FIRE ALARM	×	×	×	×	×	×	×	×	×	×	×	×

- REMARKS:
- FOR ALL MATERIALS FOR CONSTRUCTION, INSTALLATION REQUIREMENTS AND TESTING REQUIREMENTS, REFER TO CONTRACT SPECIFICATIONS.
 - BEFORE PURCHASE OR FABRICATION OF EQUIPMENT AND WITHIN 30 DAYS OF AWARD OF GENERAL CONTRACT, CONTRACTOR SHALL SUBMIT TO THE ARCHITECT/ENGINEER FOR APPROVAL, PDF COPIES OF SHOP DRAWINGS FOR ALL EQUIPMENT, LIGHTING, DEVICES, AND MATERIALS. PARTIAL OR INCOMPLETE SUBMITTALS WILL NOT BE ACCEPTED. ANY MATERIAL USED WITHOUT APPROVAL WILL BE REJECTED. SUBMIT SHOP DRAWINGS TO MECHANICAL AND PLUMBING CONTRACTOR FOR APPROVAL AND COORDINATION.
 - AN OPERATING MANUAL AND MAINTENANCE MANUAL SHALL BE PROVIDED TO THE BUILDING OWNER, WITHIN 90 DAYS OF THE DAY OF RECEIVING THE CERTIFICATE OF OCCUPANCY, PER 7TH EDITION OF THE FLORIDA BUILDING CODE - ENERGY CONSERVATION C408.3.2.2. INCLUDE AT A MINIMUM THE FOLLOWING:
 - SUBMITTAL DATA STATING EQUIPMENT RATING AND SELECTED OPTIONS FOR EACH PIECE OF EQUIPMENT REQUIRING MAINTENANCE.
 - OPERATION MANUALS AND MAINTENANCE MANUALS FOR EACH PIECE OF EQUIPMENT REQUIRING MAINTENANCE. REQUIRED ROUTINE MAINTENANCE ACTIONS SHALL BE CLEARLY IDENTIFIED.
 - NAMES AND ADDRESSES OF AT LEAST ONE QUALIFIED SERVICE AGENCY.
 - ELECTRICAL GEAR INCLUDES ALL SWITCHBOARDS, PANELBOARDS, TRANSFORMERS, SURGE PROTECTION DEVICES, MOTOR CONTROLLERS, DISCONNECTS, ETC.
 - CONTRACTOR SHALL SUBMIT ALL ITEMS UNDER ONE SUBMITTAL THAT REFERENCES DDC PROJECT NUMBER. NO PARTIAL SUBMITTALS WILL BE ACCEPTED.

- SUBMITTAL TYPE:
- FOR REVIEW
 - FOR RECORD
 - COLOR SELECTION
 - SAMPLE

CODE COMPLIANCE REQUIREMENTS

ALL WORK SHALL BE IN COMPLIANCE WITH THE FOLLOWING CODES, BUT NOT LIMITED TO:

- 8TH EDITION OF THE 2023 FLORIDA BUILDING CODE - BUILDING (FBCB)
- 8TH EDITION OF THE 2023 FLORIDA BUILDING CODE - EXISTING BUILDING (FBCBE)
- 8TH EDITION OF THE 2023 FLORIDA BUILDING CODE - ACCESSIBILITY (FBCA)
- 8TH EDITION OF THE 2023 FLORIDA BUILDING CODE - ENERGY CONSERVATION (FBCCE)
- 8TH EDITION OF THE 2014 FLORIDA PLUMBING CODE (FPCB)
- 8TH EDITION OF THE 2023 FLORIDA BUILDING CODE - PLUMBING (FBCP)
- 8TH EDITION OF THE 2023 FLORIDA BUILDING CODE - FUEL GAS (FBCFG)
- 8TH EDITION OF THE 2023 FLORIDA FIRE PROTECTION CODE (FFPC)
- NFPA 70 - 2020 NATIONAL ELECTRICAL CODE (NEC)
- 2014 STATE REQUIREMENTS FOR EDUCATIONAL FACILITIES (SREF)
- MARION COUNTY PUBLIC SCHOOLS STANDARDS

A AMPERES	KMIL THOUSAND OF CIRCULAR MILS
AC ALTERNATING CURRENT OR AIR CONDITIONER	KVA KILOVOLT-AMPERES
ADA AMERICANS W/ DISABILITIES ACT	KW KILOWATT
APC ABOVE FINISHED COUNTER	LT LIGHTING
AFF ABOVE FINISHED FLOOR	MCM THOUSANDS OF CIRCULAR MILS
APG ABOVE FINISHED GRADE	MCB MAIN CIRCUIT BREAKER
AHU AIR HANDLING UNIT	MOTOR MOTOR CIRCUIT PROTECTION
AIC AMPS INTERRUPTING CAPACITY	MCU MASTER OR MOTOR CONTROL UNIT
AWG AMERICAN WIRE GAUGE	MH METAL HALIDE
C CONDUIT	MH MAIN LUG ONLY
CATV CABLE TELEVISION	NL NIGHT LIGHT
CH COUNTER HEIGHT	NA NOT APPLICABLE
COND CONDUIT	NEC NATIONAL ELECTRIC CODE
CU COPPER OR CONDENSER UNIT	NEMA NATIONAL ELECTRICAL MANUFACTURERS ASS.
DISC DISCONNECT	NF NON-FUSED
ECB ENCLOSED CIRCUIT BREAKER	NFPA NATIONAL FIRE PROTECTION ASSOCIATION
EF EXHAUST FAN	NIC NOT IN CONTRACT
ELEC ELECTRICAL	NT NEUTRAL
EMS ENERGY MANAGEMENT SYSTEM	O.C. ON CENTER
EMT ELECTRICAL METALLIC TUBING	P POLE
ETR EXISTING TO REMAIN	PNL PANELBOARD
EWC ELECTRIC WATER COOLER	PVC POLYVINYL CHLORIDE
EWX ELECTRIC WATER HEATER	RGS RIGID GALVANIZED STEEL
EX EXISTING	RM ROOM
EXIST EXISTING	RTU ROOF TOP UNIT
FA FIRE ALARM	SS SUPER SAVER OR STAINLESS STEEL
FACP FIRE ALARM CONTROL PANEL	TBH TELEPHONE/COMPUTER TERMINAL BOARD
G GROUND	U UNLESS OTHERWISE NOTED
GFI GROUND FAULT INTERRUPTER	V VOLTS
GND GROUND	VAV VARIABLE AIR VOLUME
GRG HEATING, VENTILATING AND AIR CONDITIONING	VFD VARIABLE FREQUENCY DRIVE
J JUNCTION	W WIRE
KAIC (THOUSAND) AMPERE INTERRUPTING CAPACITY	WP WEATHERPROOF

GENERAL DEMOLITION NOTES

- A. THE CONTRACTOR SHALL VISIT AND CAREFULLY EXAMINE THOSE PORTIONS OF THE BUILDING AND SITE AFFECTED BY THIS WORK BEFORE SUBMITTING PROPOSAL SO AS TO BECOME FAMILIAR WITH EXISTING WORK. SUBMISSION OF A PROPOSAL WILL BE CONSTRUED AS EVIDENCE THAT SUCH EXAMINATION HAS BEEN MADE AND LATER CLAIMS FOR LABOR, EQUIPMENT OR MATERIALS REQUIRED BECAUSE OF DIFFICULTIES ENCOUNTERED WILL NOT BE RECOGNIZED. IT IS TO BE UNDERSTOOD THAT UNFORESEEN CONDITIONS PROBABLY EXIST AND NEW WORK MAY NOT BE FIELD LOCATED EXACTLY AS SHOWN ON THE DRAWINGS. COOPERATION WITH OTHER TRADES IN EQUIPMENT ROUTING AS DETERMINED DURING CONSTRUCTION AND AS DIRECTED BY THE ARCHITECT-ENGINEER IS NECESSARY AND IT IS INTENDED THAT SUCH DEVIATIONS SHALL BE CONSIDERED AS PART OF THIS CONTRACT. IT IS ALSO UNDERSTOOD THAT THE PLANS ARE NOT COMPLETELY TO SCALE. THIS CONTRACTOR IS TO FIELD VERIFY DIMENSIONS OF ALL EXISTING CONDITIONS, PRIOR TO BID AND INCLUDE ANY DEVIATIONS IN THE CONTRACT.
- B. ALL DEVICES AND EQUIPMENT NOT SHOWN AND IN AREAS OUTSIDE OF REMODELING SHALL REMAIN ACTIVE UNLESS OTHERWISE NOTED. INSTALL AS REQUIRED TO MAINTAIN CONTINUITY AND POWER CONNECTIONS TO EXISTING DEVICES AND EQUIPMENT THAT ARE TO REMAIN.
- C. ALL EQUIPMENT AND MATERIAL REMOVED AND NOT REUSED SHALL BE TURNED OVER TO THE OWNER OR AT THE OWNER'S REQUEST LEGALLY DISPOSED OF BY THE CONTRACTOR.
- D. ALL ELECTRICAL DEVICES THAT ARE REMOVED SHALL BE REMOVED AS DIRECTED BY THE OWNER, AND CEILING OR WALL SHALL BE PATCHED TO MATCH EXISTING OR NEW FINISH. ALL PATCHES OR CEILING PLATES SHALL BE PATCHED AND PAINTED AS DIRECTED BY ARCHITECTURAL DRAWINGS.
- E. ALL EXISTING ELECTRICAL EQUIPMENT IS NOT SHOWN. IT IS THE CONTRACTORS RESPONSIBILITY TO BECOME FAMILIAR WITH ALL EXISTING CONDITIONS PRIOR TO BID, AND INCLUDE IN HIS BID THE REMOVAL OF ALL EQUIPMENT, CONDUIT, WIRE, ETC. THAT IS NOT BEING REUSED BACK TO ITS SOURCE.
- F. ALL CONCRETE, WALL PATCHING, CEILING REPAIR, AND OTHER GENERAL WORK REQUIRED FOR INSTALLING THE ELECTRICAL SYSTEMS AND TO REPAIR TO "LIKE NEW CONDITION" TO BE PROVIDED AND INSTALLED BY THE CONTRACTOR.
- G. PROVIDE AND INSTALL ANY ADDITIONAL HANGERS/SUPPORTS REQUIRED TO ACCOMMODATE ANY EQUIPMENT RELOCATIONS.
- H. COORDINATE ALL CEILING MOUNTED DEVICES WITH ARCHITECTURAL REFLECTED CEILING AND WORK OF ALL OTHER TRADES.
- I. FOR NEW ELECTRICAL DEVICES WITHIN EXISTING WALL PARTITIONS, CONTRACTOR SHALL BE PERMITTED TO USE CONCEALED METAL CLAD CABLE. PROVIDE SUBMITTAL PRIOR TO ROUGH-IN.
- J. ITEMS NOTED AS EXISTING TO BE REMOVED SHALL BE REMOVED COMPLETE. REMOVAL SHALL INCLUDE CONDUIT AND WIRE BACK TO BRANCH PANEL.
- K. FOR ALL PANELS AFFECTED BY RENOVATION, CONTRACTOR SHALL TRACK ALL EXISTING CIRCUITS AND REMOVE WIRING AND CONDUIT BACK TO PANEL FOR CIRCUITS NO LONGER IN USE. PROVIDE NEW TYPED PANEL DIRECTORY AND RELABEL ALL UNUSED CIRCUIT BREAKERS AS SPARE.
- L. THE WORK SHALL INCLUDE REVISIONS, DEMOLITION, MODIFICATIONS AND REWORK OF THE EXISTING FACILITY AND SYSTEMS AS REQUIRED FOR INSTALLATION OF NEW WORK, AND FOR CONNECTIONS BETWEEN EXISTING WORK AND NEW WORK WHERE REQUIRED. THE WORK SHALL ALSO INCLUDE THE COMPLETION OF ELECTRICAL POWER AND CONTROL CIRCUITS, FOR DEVICES AND EQUIPMENT THAT ARE TO REMAIN IN SERVICE, IF THE CIRCUITS ARE BROKEN BY DEMOLITION WORK, OR BY THE REMOVAL OR CUTTING OF EXISTING BUILDING CONSTRUCTION, EXISTING DEVICES OR EQUIPMENT. EXISTING CONDUIT WIRING SHALL BE REROUTED AND CONNECTED WHERE NECESSARY.



4083 South U.S. Highway 1, Ste. 101
Rockledge, Florida 32955
Phone 321.633.4522 Fax 321.633.4528
www.ddc-engineers.com
dasilva.david@ddc-engineers.com
C.O.A. - 25988
DDC PROJECT NO.: 25007.01

David A. DaSilva
54739

THIS ITEM HAS BEEN DIGITALLY SIGNED AND SEALED BY DAVID A. DASILVA ON THE DATE ADJACENT TO THE SEAL. PRINTED COPIES OF THIS DOCUMENT ARE NOT CONSIDERED SIGNED AND SEALED AND THE SIGNATURE MUST BE VERIFIED ON ANY ELECTRONIC COPIES.

REVISIONS

DOCUMENT HISTORY

DESCRIPTION

NO.

DATE

HOLLY HILL SCHOOL

REPLACE BOILER

VCS Project NO. 2648219

1500 CENTER AVENUE,
HOLLY HILL, FL. 32117

ENGINEER OF RECORD

ENGINEER
DAVID A. DASILVA


DESIGNED BY

DAD

DRAWN BY



IO/HR

ISSUE DATE

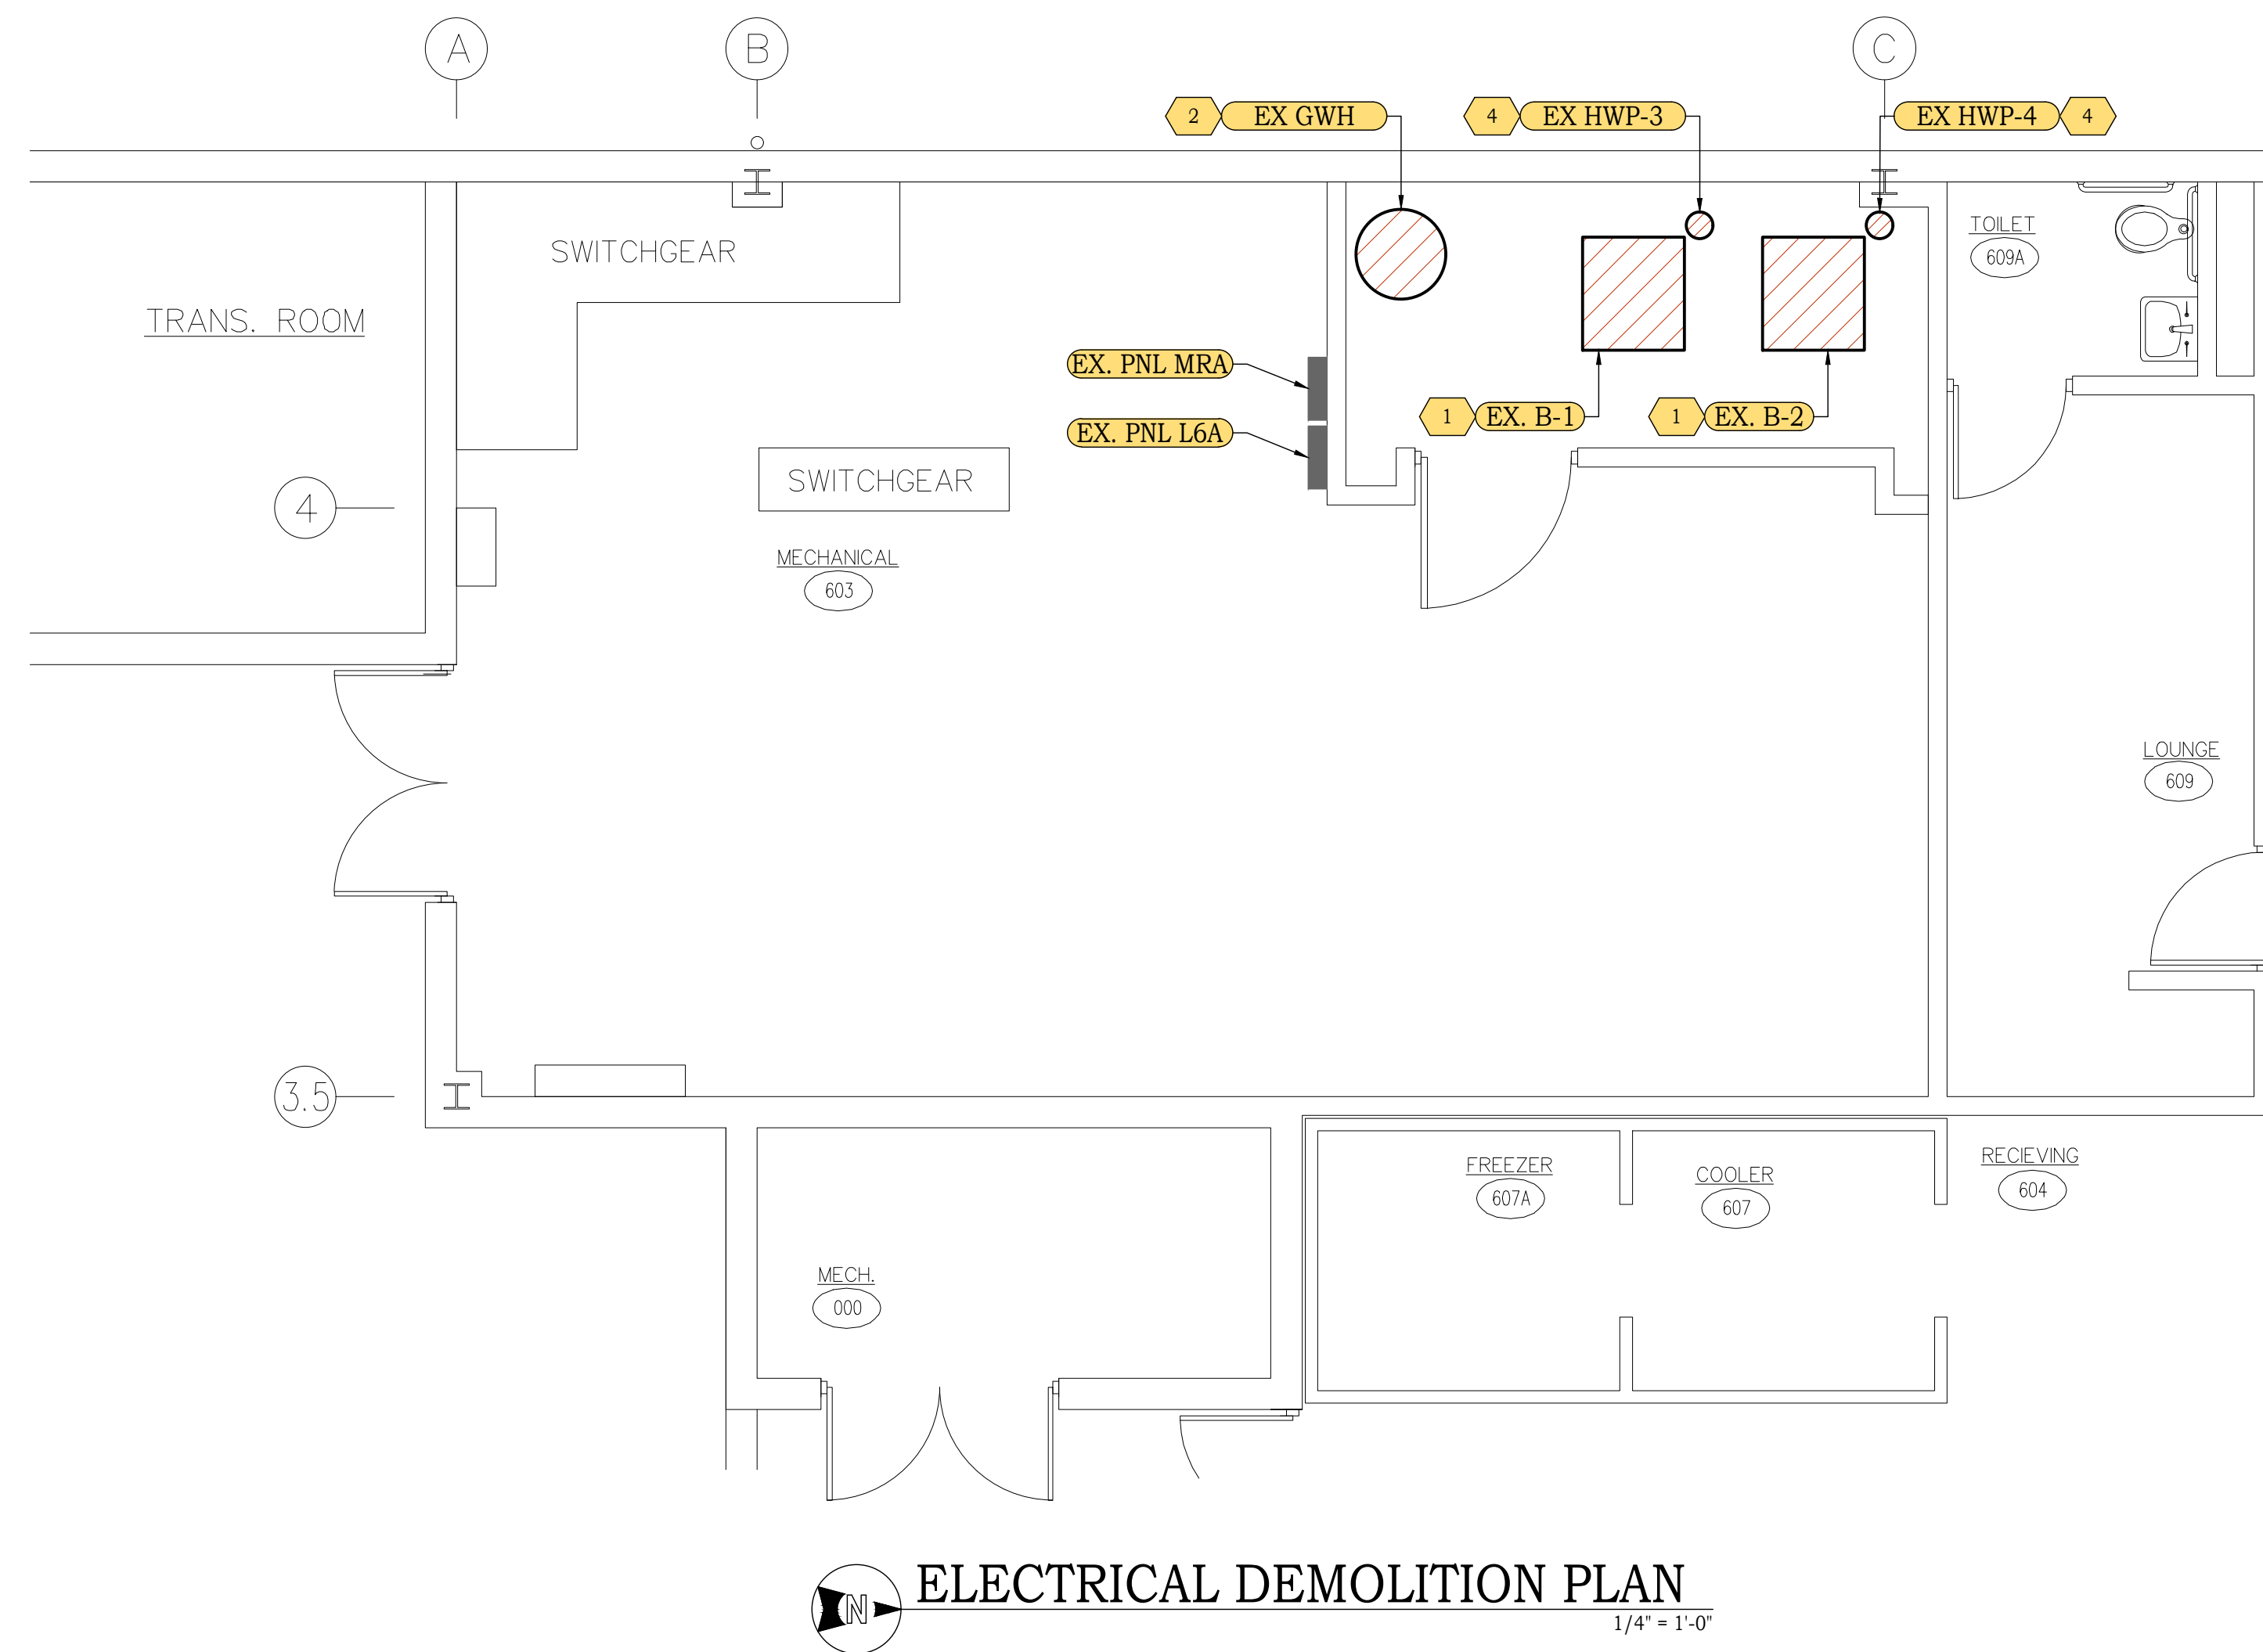

PLAN NOTES

1. EXISTING BOILER SHALL BE REMOVED AND REPLACED WITH NEW. CONTRACTOR SHALL REMOVE ALL ASSOCIATED DEVICES, CONDUITS, WIRING, ETC., BACK TO SOURCE PANEL MRA. RE-LABEL UN-USED CIRCUIT AS SPARE. PROVIDE NEW TYPE WRITTEN PANEL DIRECTORY.
2. EXISTING WATER HEATER SHALL BE REMOVED AND REPLACED WITH NEW. EXISTING GAS WATER HEATER IS PLUGGED INTO EXISTING RECEPTACLE IN ROOM.
3. NEW WATER HEATER SHALL BE PLUGGED INTO EXISTING RECEPTACLE WITHIN ROOM.
4. EXISTING BOILER PUMP SHALL BE REMOVED AND REPLACED WITH NEW. CONTRACTOR SHALL REMOVE ALL ASSOCIATED DEVICES, CONDUITS, WIRING, ETC., BACK TO SOURCE PANEL MRA. RE-LABEL UN-USED CIRCUIT AS SPARE. PROVIDE NEW TYPE WRITTEN PANEL DIRECTORY.

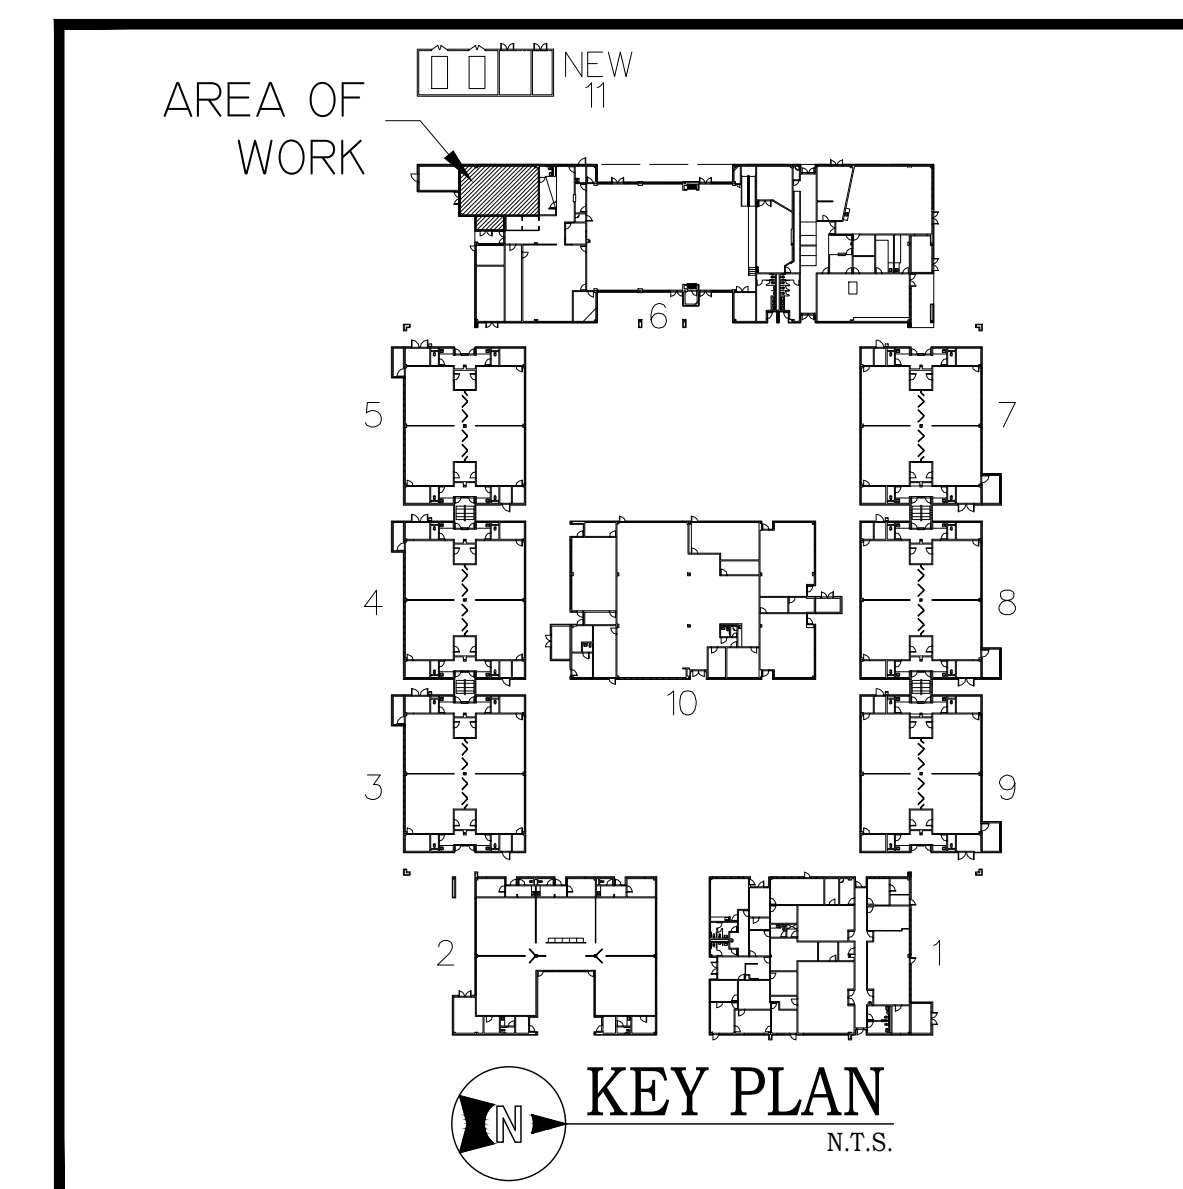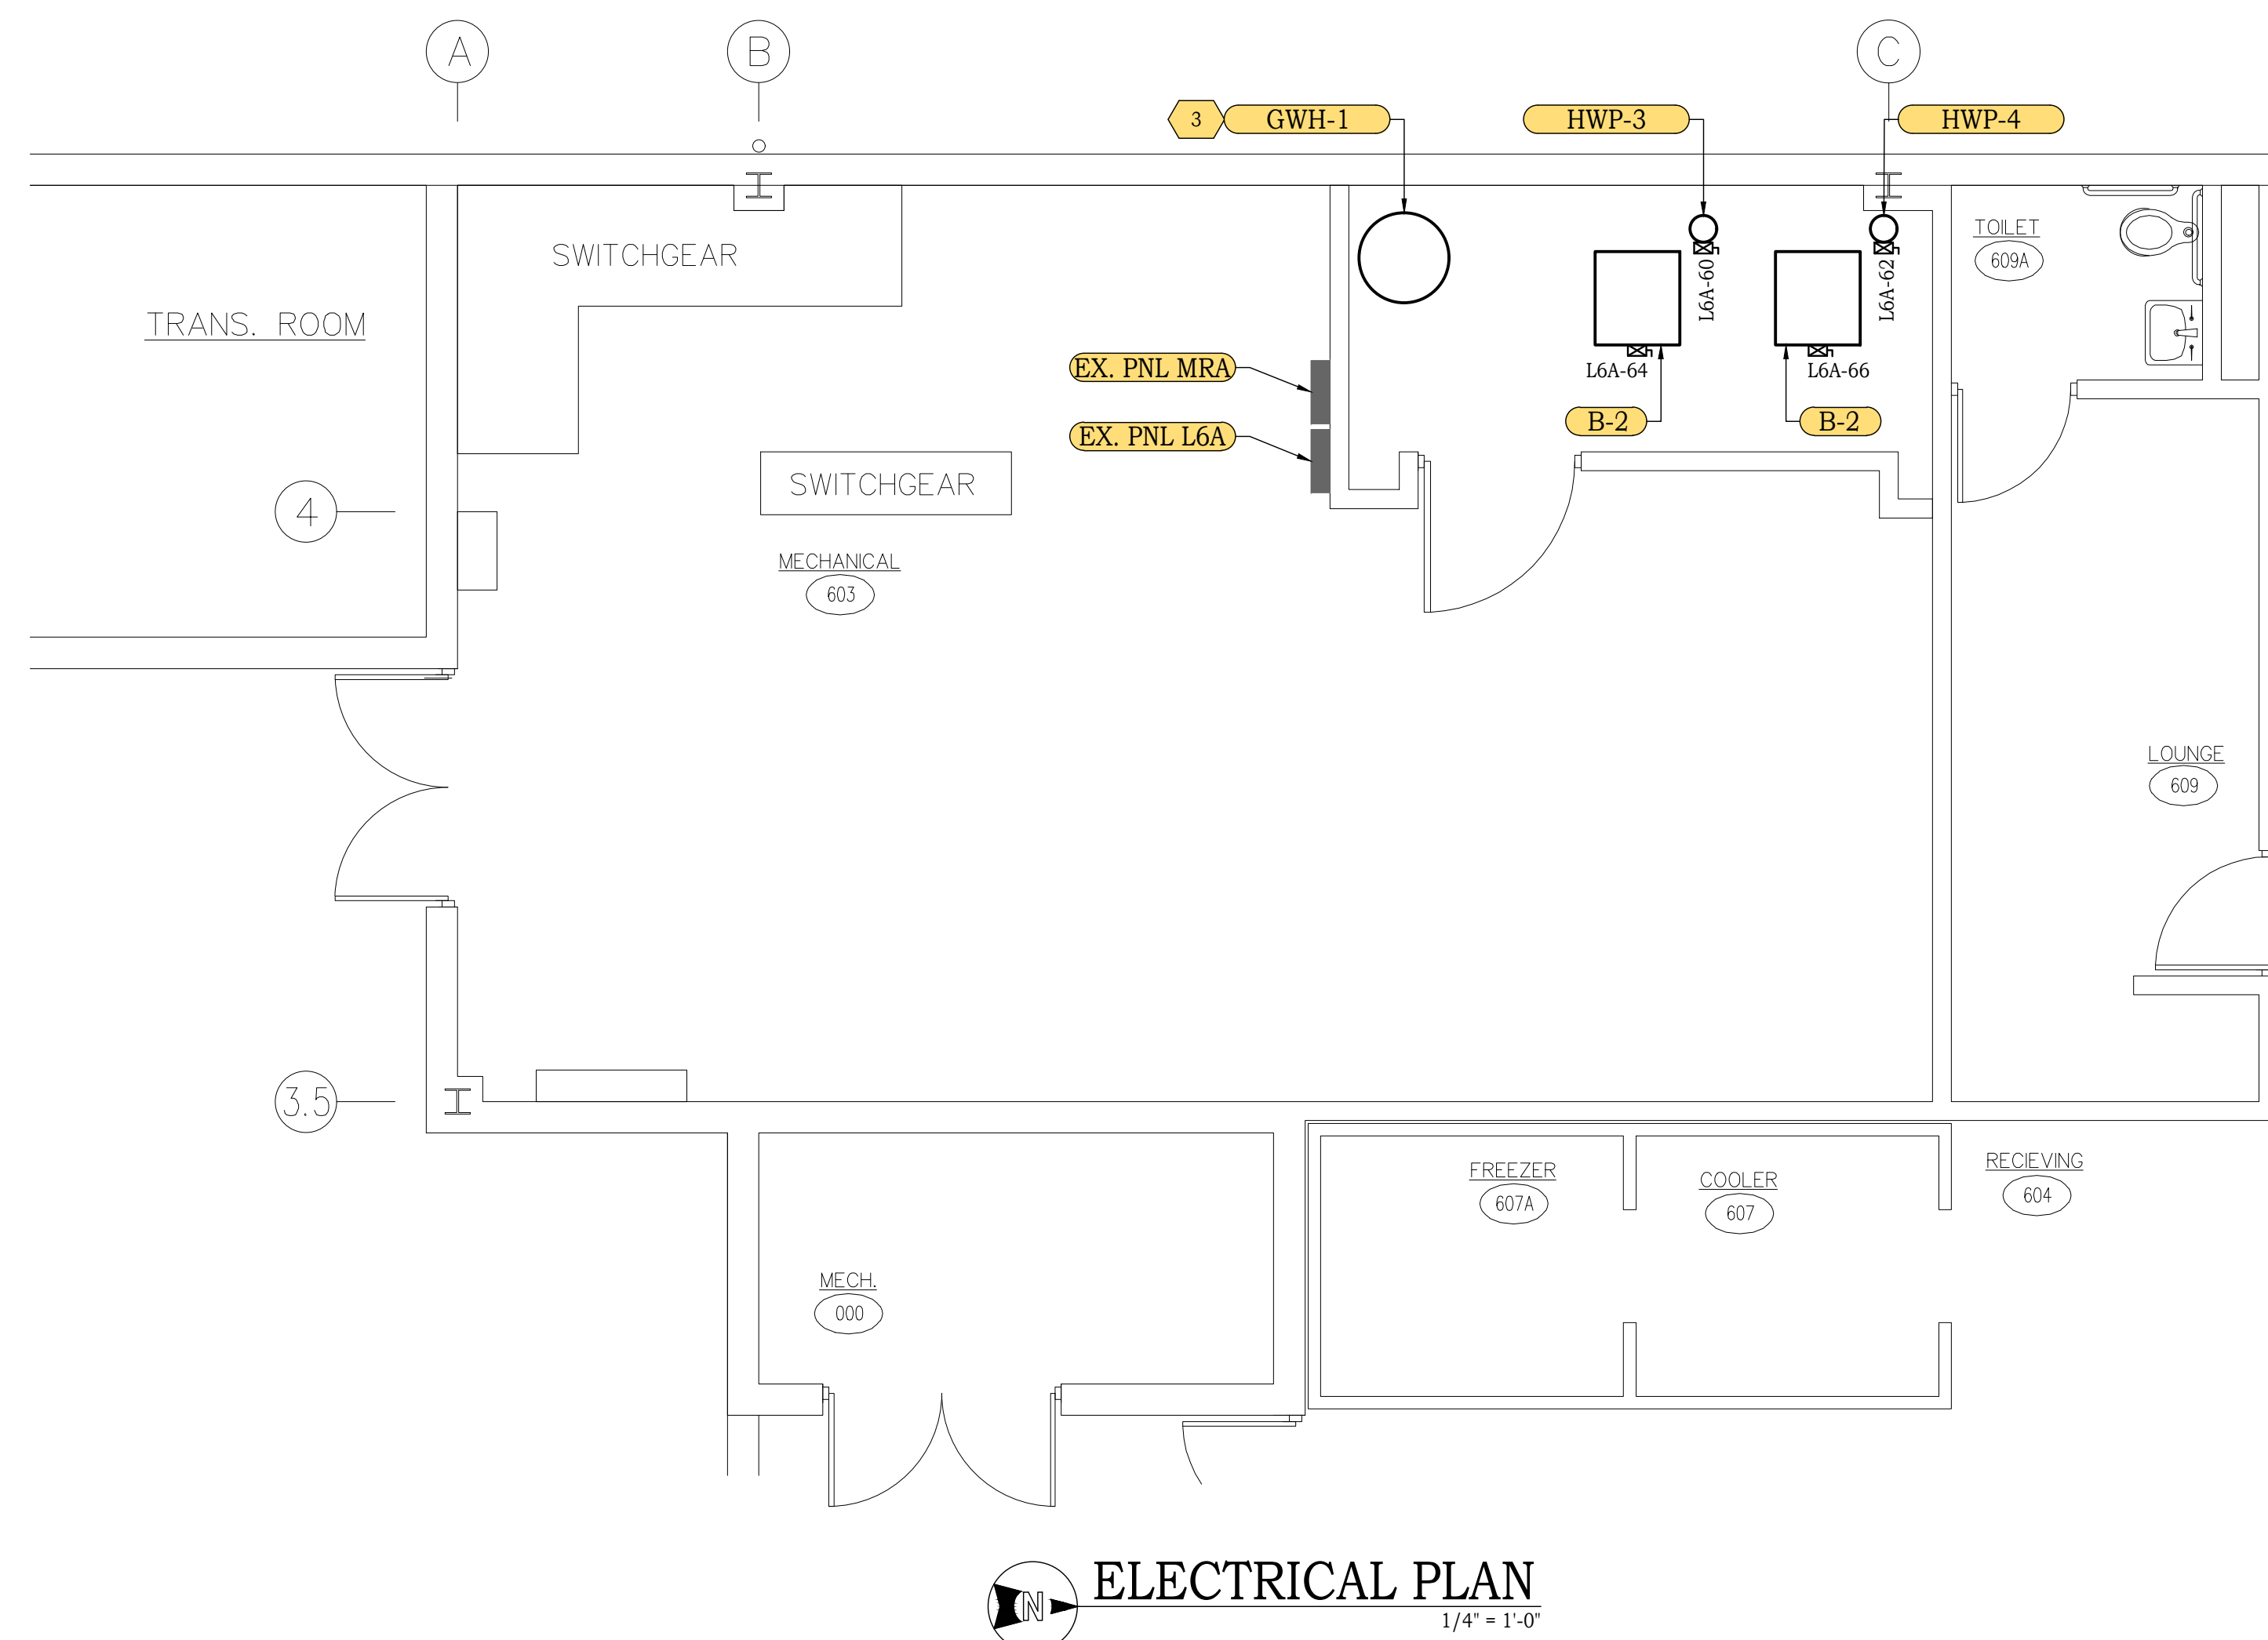

4083 South U.S. Highway 1, Ste. 101
Rockledge, Florida 32955
Phone 321.633.4522 Fax 321.633.4528
www.ddc-engineers.com
dasilva.david@ddc-engineers.com
C.O.A.: 25988
DDC PROJECT NO.: 25007.01

David A. DaSilva
54739

THIS ITEM HAS BEEN DIGITALLY SIGNED AND SEALED BY DAVID A. DASILVA ON THE DATE ADJACENT TO THE SEAL. PRINTED COPIES OF THIS DOCUMENT ARE NOT CONSIDERED SIGNED AND SEALED AND THE SIGNATURE MUST BE VERIFIED ON ANY ELECTRONIC COPIES.

REVISIONS


DOCUMENT HISTORY
NO. DATE DESCRIPTION

HOLLY HILL SCHOOL
REPLACE BOILER
VCS Project NO. 2648219
1500 CENTER AVENUE,
HOLLY HILL, FL. 32117

ENGINEER OF RECORD
ENGINEER
DAVID A. DASILVA
DESIGNED BY
DAD
DRAWN BY
IO/HR
ISSUE DATE
03/27/2026
AE PROJECT NUMBER
25007.01
SHEET TITLE
ELECTRICAL PLANS

DRAWING NO.

E100

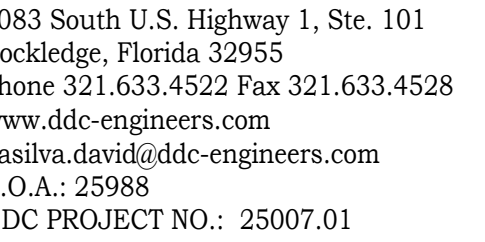

THIS ITEM HAS BEEN DIGITALLY SIGNED AND SEALED BY DAVID A. NASILVA ON THE DATE ADJACENT TO THE SEAL. PRINTED COPIES OF THIS DOCUMENT ARE NOT CONSIDERED SIGNED AND SEALED AND THE SIGNATURE MUST BE VERIFIED ON ANY ELECTRONIC COPIES.

**HOLLY HILL SCHOOL
REPLACE BOILER
VCS Project NO. 2648219
1500 CENTER AVENUE,
HOLLY HILL, FL. 32117**

E500




PANEL: L6A (EXISTING)

PANEL TYPE:		EXISTING SIEMENS		BUS AMP RATING:		250 A		VOLTAGE:		120/208		LUG LOCATION:		EXISTING	
PANEL LOCATION:		MECH. RM 603		MAIN AMP RATING:		225 A		PHASE:		3		MOUNTING:		EXISTING SURFACE	
FED FROM SOURCE:		MDP		MAIN TYPE:		MLO		WIRE:		4		AIC RATING:		EXISTING	

CKT NO.	EQUIP NO.	TYPE	EQUIPMENT SERVED	NOTES	KVA	CKT. BKR. POLE/TR	BRANCH CKT				Ø	CKT NO.	EQUIP NO.	TYPE	EQUIPMENT SERVED	NOTES	KVA	CKT. BKR. POLE/TR	BRANCH CKT				
							Ø	N	GND	C									Ø	N	GND	C	
1												2	(E)	SPARE				1/20					
3												4	(E)	SPARE				1/20					
5												6	(E)	SPARE				1/20					
7												8	(E)	SPARE				3/40					
9												10											
11												12											
13												14	(E)	SPARE				3/30					
15												16											
17												18											
19												20	(E)	SPARE				3/30					
21												22											
23												24											
25												26	(E)	SPARE				1/20					
27												28	(E)	SPARE				1/20					
29												30	(E)	SPARE				1/20					
31												32											
33												34											
35												36											
37	(E)	SPARE				1/20						38	(E)	SPARE				1/20					
39	(E)	SPARE				1/20						40	(E)	SPARE				1/20					
41	(E)	SPARE				1/20						42	(E)	SPARE				1/20					
43	(E)	SPARE				1/20						44	(E)	SPARE				1/20					
45	(E)	SPARE				1/20						46	(E)	SPARE				1/20					
47	(E)	SPARE				1/20						48	(E)	SPARE				1/20					
49	(E)	SPARE				1/20						50	(E)	SPARE				1/20					
51	(E)	SPARE				1/20						52	(E)	SPARE				1/20					
53	(E)	SPARE				1/20						54	(E)	SPARE				1/20					
55	(E)	SPARE				1/20						56	(E)	SPARE				1/20					
57	(E)	SPARE				1/20						58	(E)	SPARE				1/20					
59	(E)	SPARE				1/20						60	H **	HWP-3	HACR	1.92	1/20	12	12	12	12	3/4*	
61	(E)	SPD			0.0	3/30	EXISTING					62	H **	HWP-4	HACR	1.92	1/20	12	12	12	12	3/4*	
63												64	H **	B-1	HACR	1.92	1/20	12	12	12	12	3/4*	
65												66	H **	B-2	HACR	1.92	1/20	12	12	12	12	3/4*	

EQUIPMENT SERVED	CONN. LOAD	LF	DF	DESIGN LOAD	NOTES: TC - WIRE THROUGH CONTACTOR HACR - HACTYR TYPE BREAKER LO - LOCKOUT BREAKER GFCCI - GND FAULT CURRENT INTERRUPT CIRCUIT BREAKER IG - ISOLATED GROUND WIP - WALK IN FREEZER WIC - WALK IN COOLER	CONNECTION TYPE	REMARKS: - PROVIDE NEW TYPE WRITTEN DIRECTORY. - CONTRACTOR SHALL CONFIRM HVAC CIRCUIT BREAKER REQUIREMENTS BEFORE PURCHASING. - HEAT/COOLING LOADS ARE MUTUALLY EXCLUSIVE. ** CONTRACTOR SHALL USE EXISTING SPARE CIRCUIT BREAKERS TO SERVE NEW LOADS INDICATED.
HVAC/EWH	7.68		1.00	7.68		R - RECEPTACLE L - LIGHTING H - HVAC/EWH K - KITCHEN EQUIPMENT M - MISC. (E) - EXISTING	
TOTAL AMPS				7.68 KVA 21			

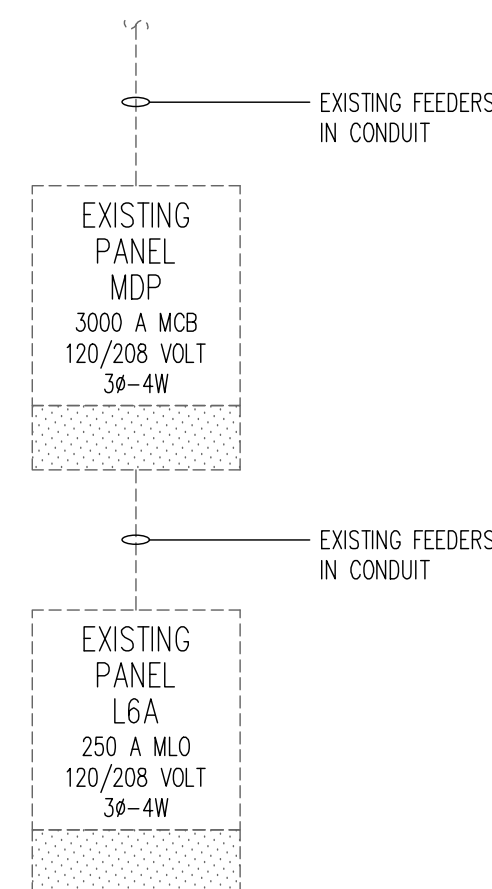

ELECTRICAL ONE-LINE DIAGRAM



4083 South U.S. Highway 1, Ste. 101
Rockledge, Florida 32955
Phone 321.633.4522 Fax 321.633.4528
www.ddc-engineers.com
dasilva.david@ddc-engineers.com
C.O.A.: 25988
DDC PROJECT NO.: 250007.01

David A. DaSilva
54739

THIS ITEM HAS BEEN DIGITALLY SIGNED AND SEALED BY DAVID A. DASILVA ON THE DATE ADJACENT TO THE SEAL. PRINTED COPIES OF THIS DOCUMENT ARE NOT CONSIDERED SIGNED AND SEALED AND THE SIGNATURE MUST BE VERIFIED ON ANY ELECTRONIC COPIES.

[illegible]

**HOLLY HILL SCHOOL
REPLACE BOILER
VCS Project NO. 2648219
1500 CENTER AVENUE,
HOLLY HILL, FL. 32117**

ENGINEER DAVID A. DASILVA	
SIGNED BY DAD	DRAWN BY JO
DATE 3/27/2026	AE PROJECT NUMBER 25007.01
EET TITLE ELECTRICAL SCHEDULE & ONE-LINE DIAGRAM	
DRAWING NO.	
E600	



PD#

- 

David A. DaSilva
54739

REVISIONS

DOCUMENT HISTORY			DESCRIPTION
NO	DATE		



**HOLLY HILL SCHOOL
REPLACE BOILER
VCS Project NO. 2648219
1500 CENTER AVENUE,
HOLLY HILL, FL. 32117**

ENGINEER OF RECORD

DRAWN BY
IO/HE

AE PROJECT NUMBER
25007.01


PLUMBING DEMOLITION PLANS

PD100




#


- # P100

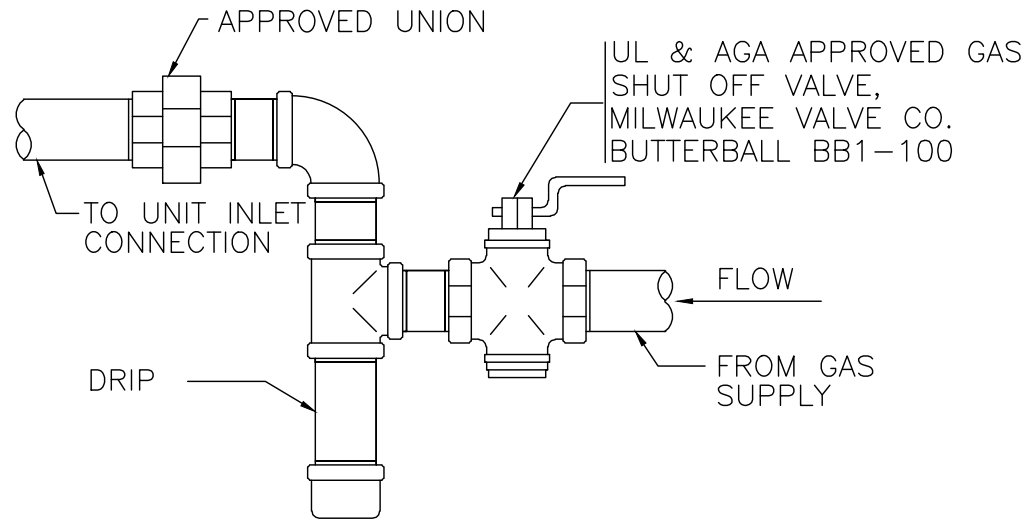


GAS CONNECTION
N.T.S.

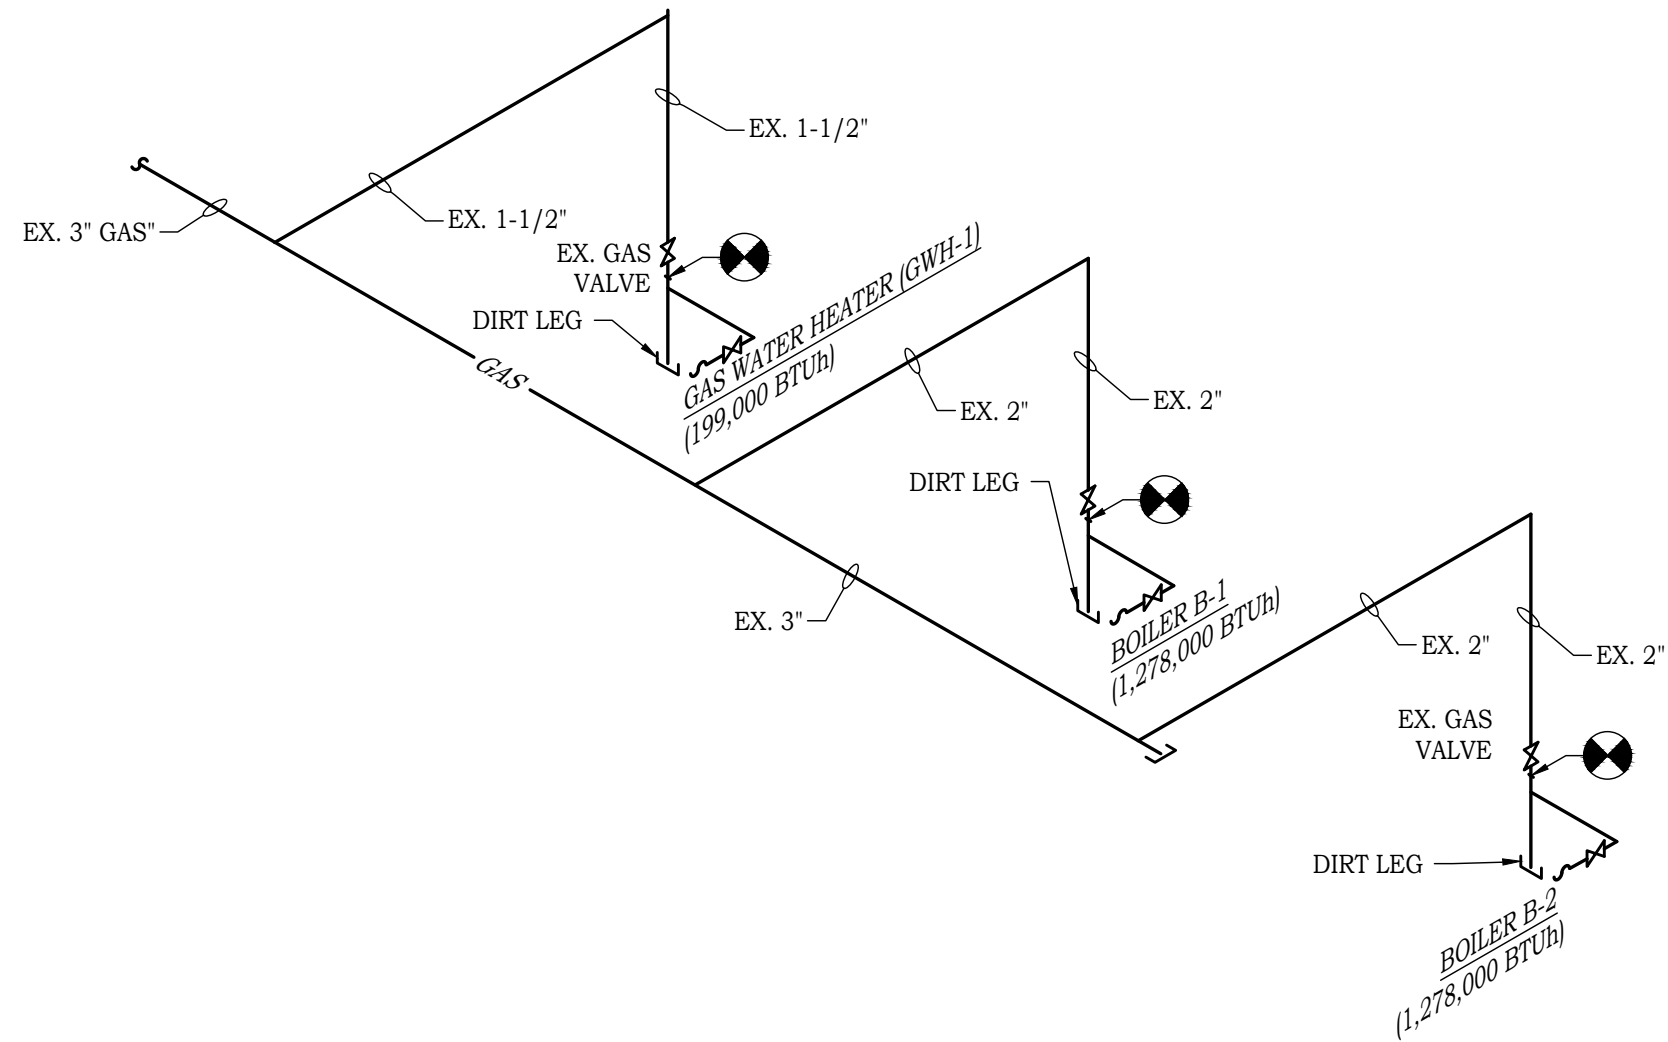

GAS RISER
N.T.S.

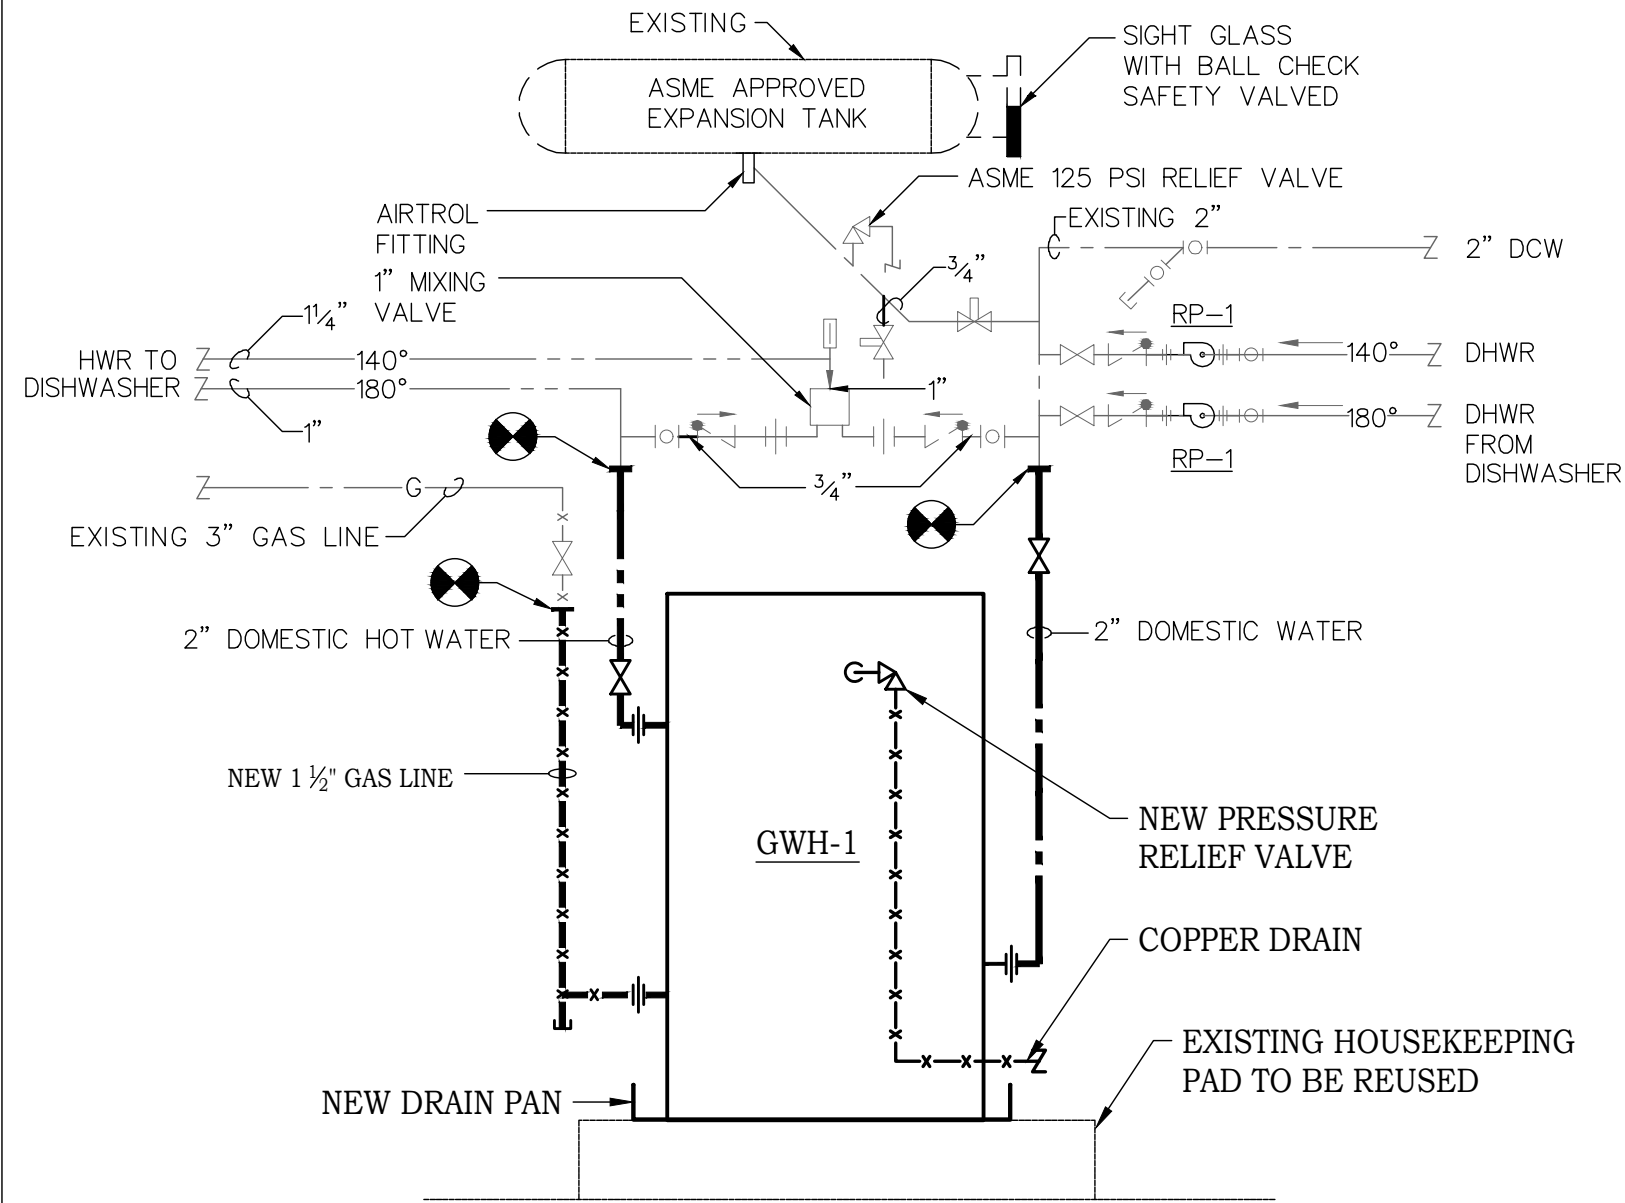

P1 WATER HEATER DETAIL
N.T.S.

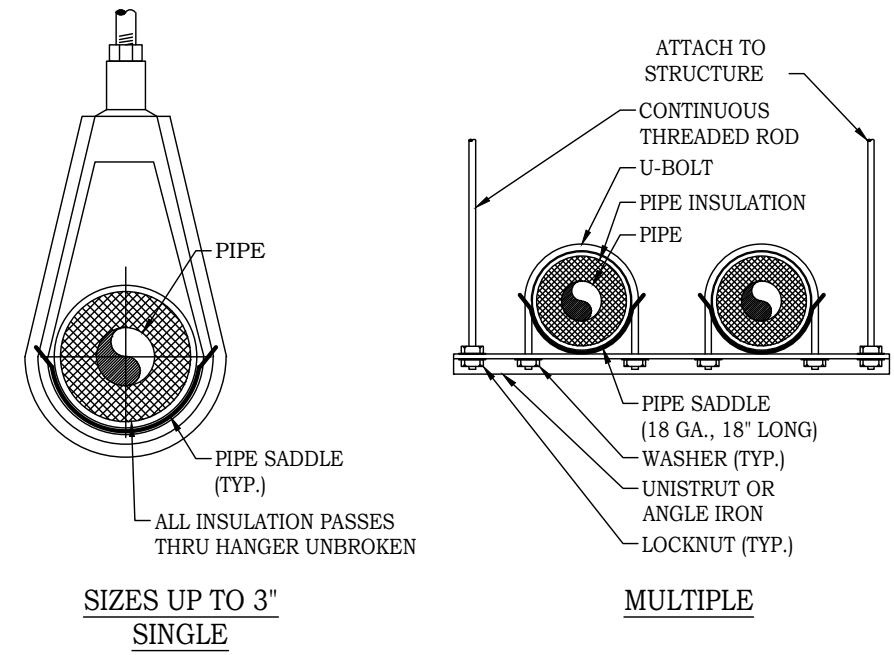

P2 INSULATED PIPE HANGER DETAIL
N.T.S.



4083 South U.S. Highway 1, Ste. 101
Rockledge, Florida 32955
Phone 321.633.4522 Fax 321.633.4528
www.ddc-engineers.com
dasilva.david@ddc-engineers.com
C.O.A.: 25988
DDC PROJECT NO.: 25007.01

David A. DaSilva
54739

THIS ITEM HAS BEEN DIGITALLY SIGNED AND SEALED BY DAVID A. DASILVA ON THE DATE ADJACENT TO THE SEAL. PRINTED COPIES OF THIS DOCUMENT ARE NOT CONSIDERED SIGNED AND SEALED AND THE SIGNATURE MUST BE VERIFIED ON ANY ELECTRONIC COPIES.

REVISIONS

DOCUMENT HISTORY

DESCRIPTION

NO. DATE

HOLLY HILL SCHOOL

REPLACE BOILER

VCS Project NO. 2648219

1500 CENTER AVENUE,
HOLLY HILL, FL. 32117

ENGINEER DAVID A. DASILVA	
DESIGNED BY DAD	DRAWN BY IO/HR
ISSUE DATE 03/27/2026	AE PROJECT NUMBER 25007.01
SHEET TITLE PLUMBING DETAILS & RISERS	

DRAWING NO.

P500