


DRAWING NAME: F:\2026\26166 - COLTON MENTAL HEALTH - MILLER_VELA\DWG | PLOT DATE: 6/30/2026 4:48 PM | PLOTTED BY: SAMUEL VELA | COPYRIGHT 2016 MILLER ARCHITECTURAL CORPORATION. ALL RIGHTS RESERVED.

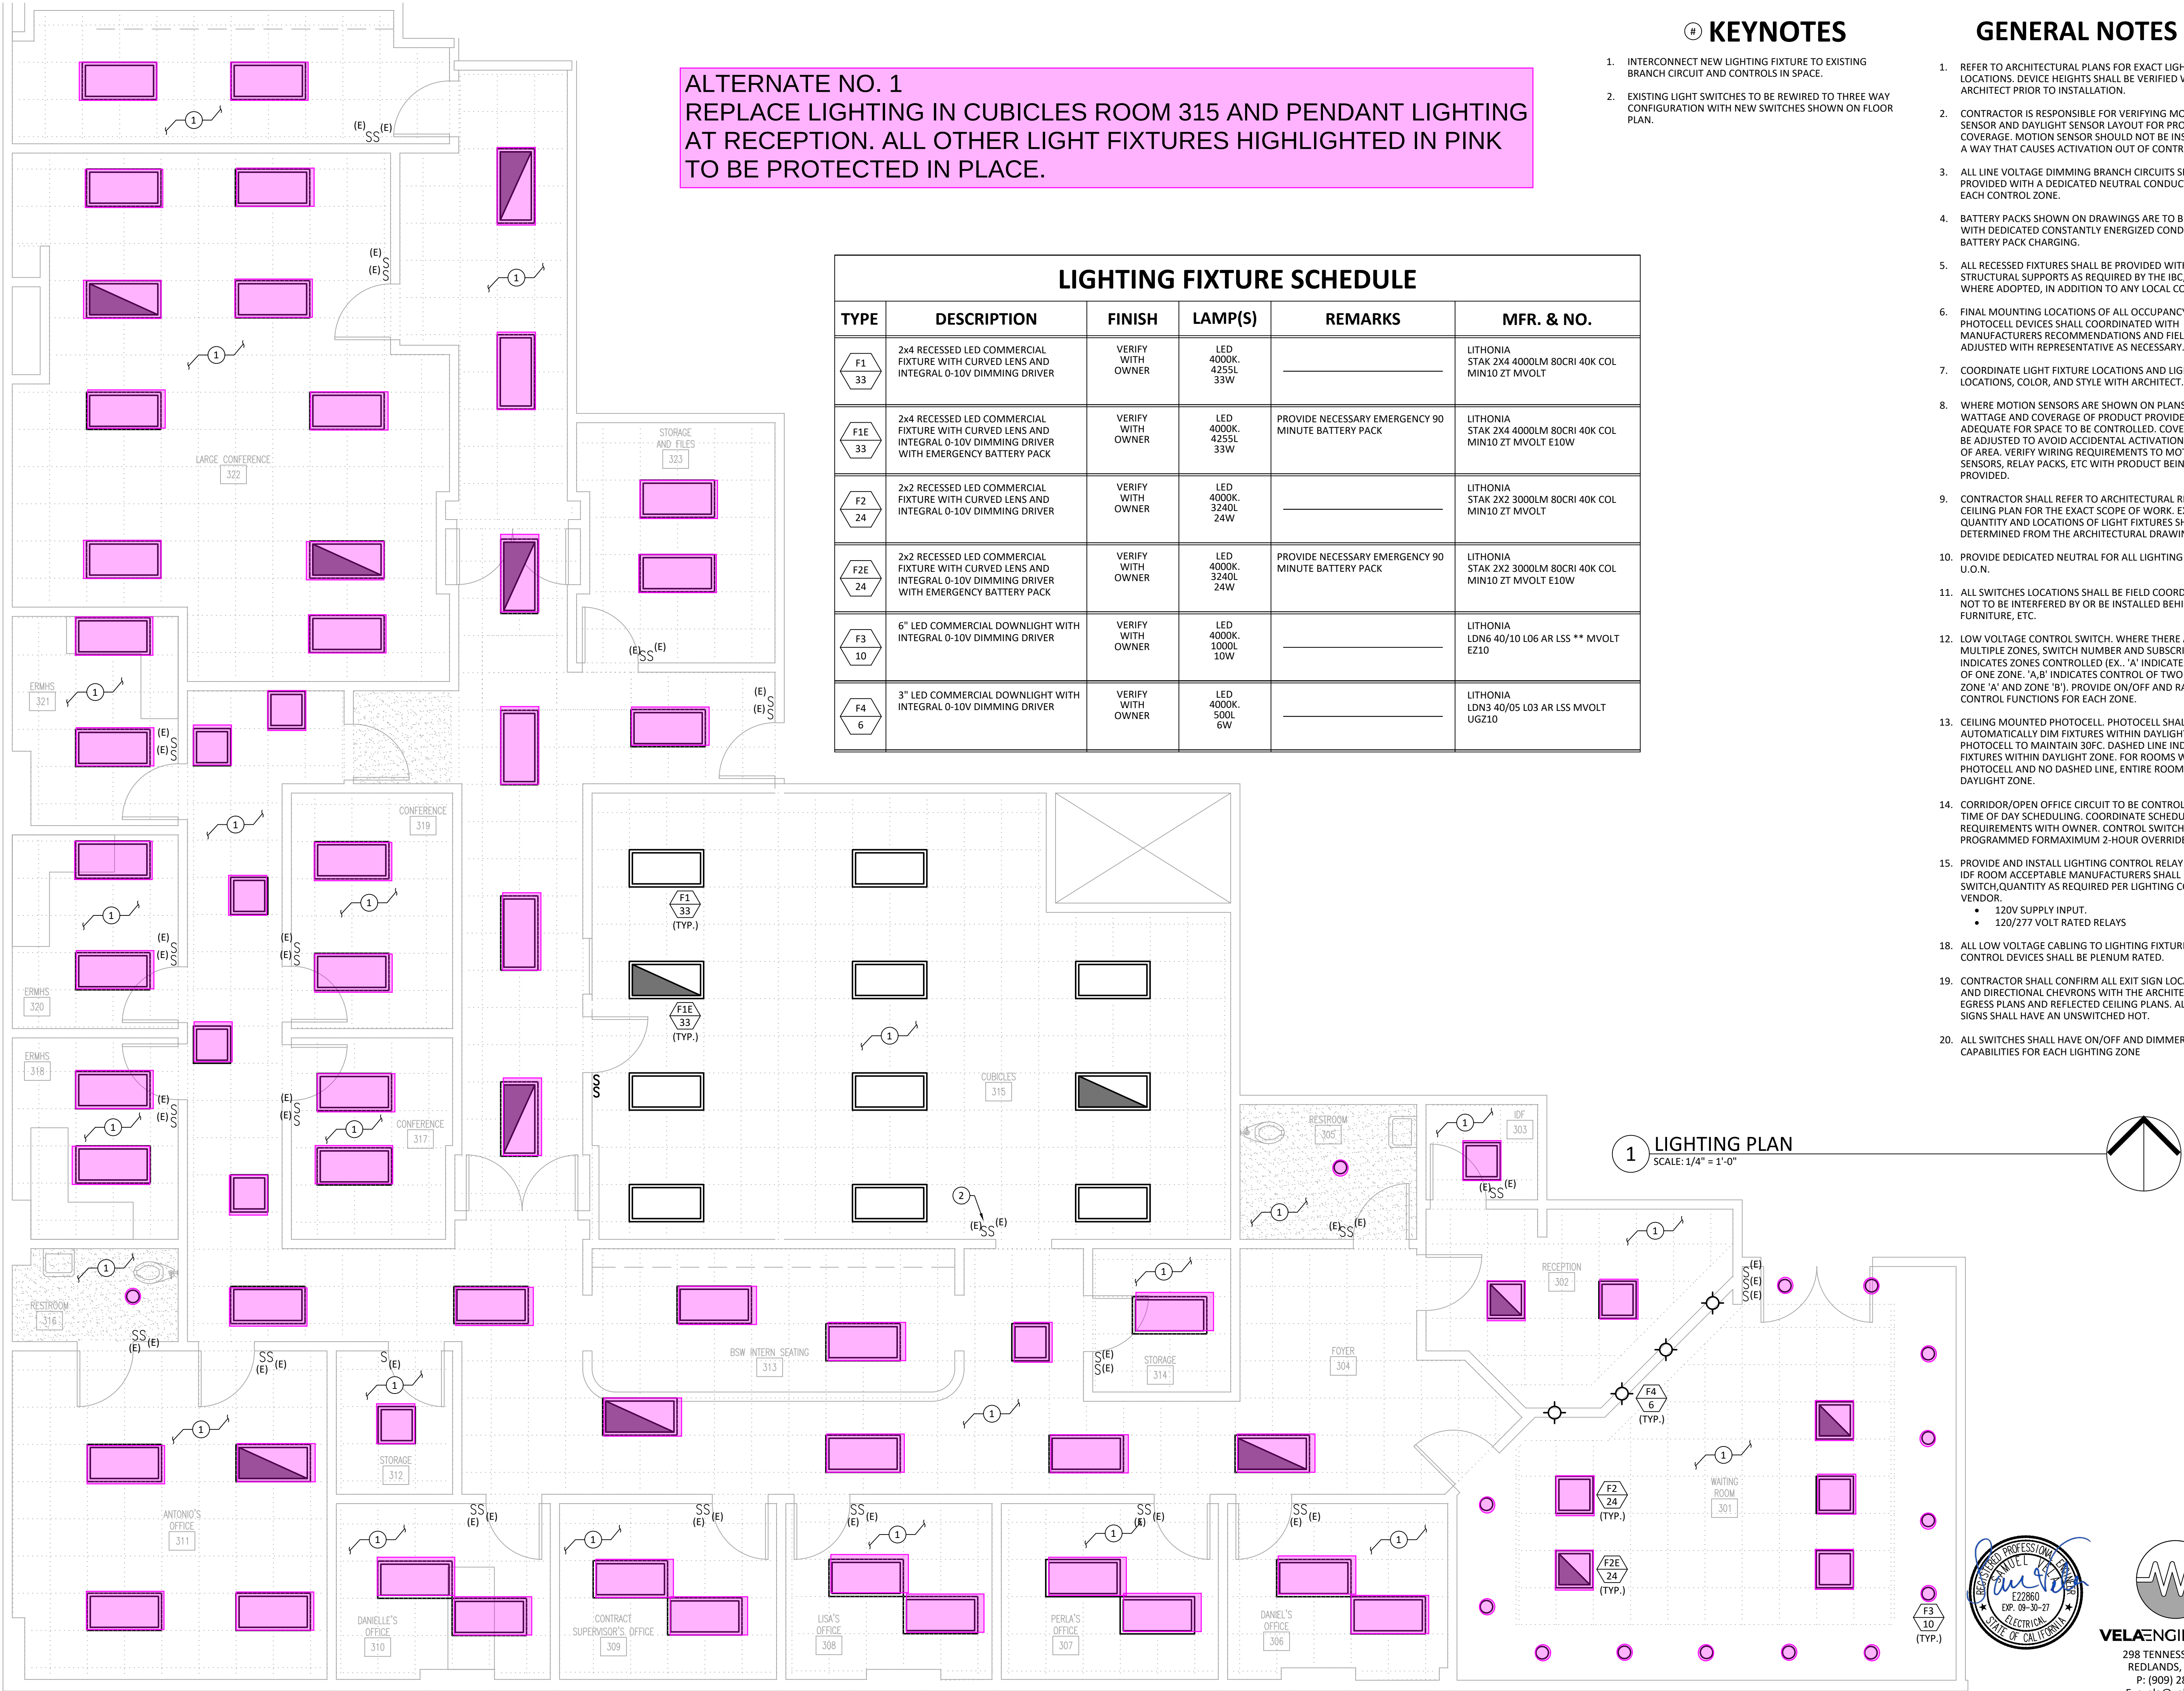

KEYNOTES

- INTERCONNECT NEW LIGHTING FIXTURE TO EXISTING BRANCH CIRCUIT AND CONTROLS IN SPACE.
- EXISTING LIGHT SWITCHES TO BE REWIRED TO THREE WAY CONFIGURATION WITH NEW SWITCHES SHOWN ON FLOOR PLAN.

GENERAL NOTES

- REFER TO ARCHITECTURAL PLANS FOR EXACT LIGHT FIXTURE LOCATIONS. DEVICE HEIGHTS SHALL BE VERIFIED WITH THE ARCHITECT PRIOR TO INSTALLATION.
- CONTRACTOR IS RESPONSIBLE FOR VERIFYING MOTION SENSOR AND DAYLIGHT SENSOR LAYOUT FOR PROPER COVERAGE. MOTION SENSOR SHOULD NOT BE INSTALLED IN A WAY THAT CAUSES ACTIVATION OUT OF CONTROL AREA.
- ALL LINE VOLTAGE DIMMING BRANCH CIRCUITS SHALL BE PROVIDED WITH A DEDICATED NEUTRAL CONDUCTOR FOR EACH CONTROL ZONE.
- BATTERY PACKS SHOWN ON DRAWINGS ARE TO BE PROVIDED WITH DEDICATED CONSTANTLY ENERGIZED CONDUCTOR FOR BATTERY PACK CHARGING.
- ALL RECESSED FIXTURES SHALL BE PROVIDED WITH ALL STRUCTURAL SUPPORTS AS REQUIRED BY THE IBC, OR CBC WHERE ADOPTED, IN ADDITION TO ANY LOCAL CODES.
- FINAL MOUNTING LOCATIONS OF ALL OCCUPANCY AND PHOTOCELL DEVICES SHALL COORDINATED WITH MANUFACTURERS RECOMMENDATIONS AND FIELD ADJUSTED WITH REPRESENTATIVE AS NECESSARY.
- COORDINATE LIGHT FIXTURE LOCATIONS AND LIGHT SWITCH LOCATIONS, COLOR, AND STYLE WITH ARCHITECT.
- WHERE MOTION SENSORS ARE SHOWN ON PLANS, VERIFY WATTAGE AND COVERAGE OF PRODUCT PROVIDED IS ADEQUATE FOR SPACE TO BE CONTROLLED. COVERAGE IS TO BE ADJUSTED TO AVOID ACCIDENTAL ACTIVATION OUTSIDE OF AREA. VERIFY WIRING REQUIREMENTS TO MOTION SENSORS, RELAY PACKS, ETC WITH PRODUCT BEING PROVIDED.
- CONTRACTOR SHALL REFER TO ARCHITECTURAL REFLECTED CEILING PLAN FOR THE EXACT SCOPE OF WORK. EXACT QUANTITY AND LOCATIONS OF LIGHT FIXTURES SHALL BE DETERMINED FROM THE ARCHITECTURAL DRAWINGS.
- PROVIDE DEDICATED NEUTRAL FOR ALL LIGHTING CIRCUITS U.O.N.
- ALL SWITCHES LOCATIONS SHALL BE FIELD COORDINATED AS NOT TO BE INTERFERED BY OR BE INSTALLED BEHIND DOORS, FURNITURE, ETC.
- LOW VOLTAGE CONTROL SWITCH. WHERE THERE ARE MULTIPLE ZONES, SWITCH NUMBER AND SUBSCRIPT INDICATES ZONES CONTROLLED (EX. 'A' INDICATES CONTROL OF ONE ZONE. 'A,B' INDICATES CONTROL OF TWO ZONES. ZONE 'A' AND ZONE 'B'), PROVIDE ON/OFF AND RAISE/LOWER CONTROL FUNCTIONS FOR EACH ZONE.
- CEILING MOUNTED PHOTOCELL. PHOTOCELL SHALL AUTOMATICALLY DIM FIXTURES WITHIN DAYLIGHT ZONE. SET PHOTOCELL TO MAINTAIN 30FC. DASHED LINE INDICATES FIXTURES WITHIN DAYLIGHT ZONE. FOR ROOMS WITH A PHOTOCELL AND NO DASHED LINE, ENTIRE ROOM IS DAYLIGHT ZONE.
- CORRIDOR/OPEN OFFICE CIRCUIT TO BE CONTROLLED VIA TIME OF DAY SCHEDULING. COORDINATE SCHEDULING REQUIREMENTS WITH OWNER. CONTROL SWITCHES TO BE PROGRAMMED FOR MAXIMUM 2-HOUR OVERRIDE.
- PROVIDE AND INSTALL LIGHTING CONTROL RELAY PANEL IN IDF ROOM. ACCEPTABLE MANUFACTURERS SHALL BE SENSOR SWITCH, QUANTITY AS REQUIRED PER LIGHTING CONTROL VENDOR.
 - 120V SUPPLY INPUT.
 - 120/277 VOLT RATED RELAYS
- ALL LOW VOLTAGE CABLING TO LIGHTING FIXTURES AND CONTROL DEVICES SHALL BE PLENUM RATED.
- CONTRACTOR SHALL CONFIRM ALL EXIT SIGN LOCATIONS AND DIRECTIONAL CHEVRONS WITH THE ARCHITECTURAL EGRESS PLANS AND REFLECTED CEILING PLANS. ALL EXIT SIGNS SHALL HAVE AN UNSWITCHED HOT.
- ALL SWITCHES SHALL HAVE ON/OFF AND DIMMER CAPABILITIES FOR EACH LIGHTING ZONE



architecture
interiors
planning

1177 Idaho Street, Suite 200
Redlands, CA 92374
Phone: (909) 335-7400
Fax: (909) 335-7299
info@miller-aip.com



owner approval

initials	date	phase
	00/00/00	--

revisions/addenda

mark	date	comment
A	00/00/00	--
B		
C		
D		
E		
F		
G		

900 WASHINGTON ST.
MENTAL HEALTH T.I.
900 EAST WASHINGTON STREET
COLTON, CA 92324

COLTON JOINT UNIFIED
SCHOOL DISTRICT
1212 VALENCIA DRIVE
COLTON, CA 92324
CONTACT: JAMIE LUNGREN PHONE:

project information


PROJECT NO: 2600013.RA
DWG FILE: E_LTGPLAN.DWG
DRAWN BY:
CHECKED BY: GWM
DRAWING SCALE:
DATE: 6/30/2026

sheet name

ALTERNATE NO. 1

sheet number

EXHIBIT ALT 1

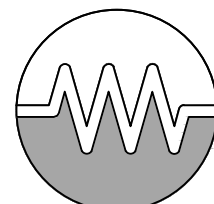

VELA ENGINEERING
298 TENNESSEE STREET
REDLANDS, CA 92373
P: (909) 281-8100
E: svela@velaeng.com