


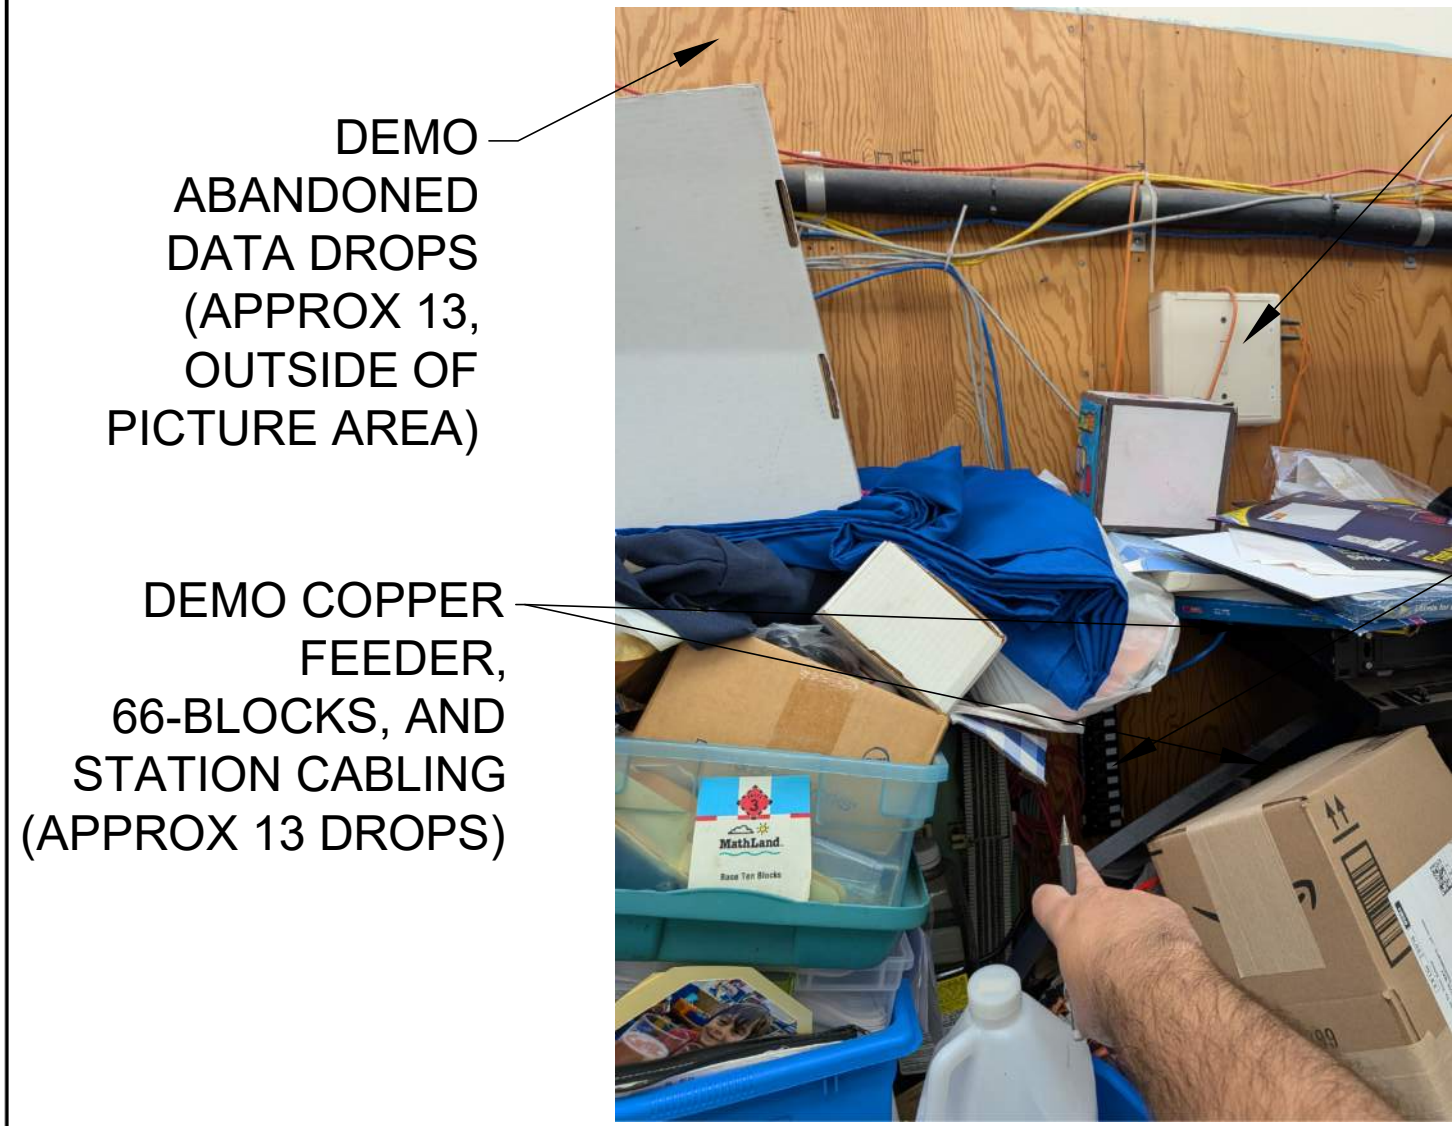


DEMO
ABANDONED
DATA DROPS
(APPROX 13,
OUTSIDE OF
PICTURE AREA)

DEMO COPPER
FEEDER,
66-BLOCKS, AND
STATION CABLING
(APPROX 13 DROPS)



DEMO MM
FIBER AND
PATCH PANEL

DEMO CAT5
PATCH PANEL

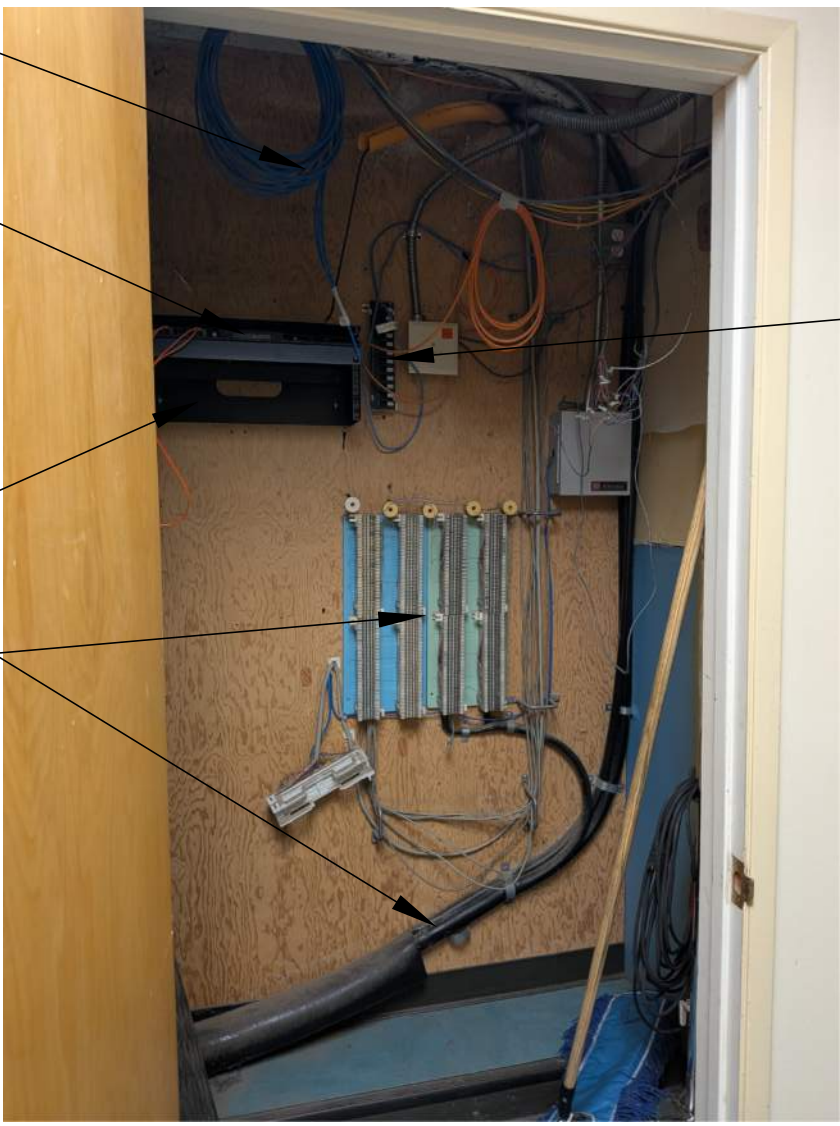

DEMO CUT
CAT CABLES

DEMO MM
FIBER AND
PATCH PANEL

DEMO SHELF

DEMO COPPER
FEEDER,
66-BLOCKS,
AND STATION
CABLES



DEMO CAT5
PATCH PANEL
AND STATION
CABLES

DEMO COPPER
FEEDER,
66-BLOCKS,
AND STATION
CABLES

DEMO MM FIBER
AND PATCH PANEL

GENERAL NOTES:	
1.	NO STRUCTURAL BEAMS SHALL BE PENETRATED OR ALTERED.
2.	ALL EQUIPMENT AND MATERIALS ARE CONTRACTOR FURNISHED, INSTALLED, AND CONFIGURED, UNO.
3.	CONTRACTOR SHALL TOUCH UP PAINT TO MATCH EXISTING CONDITIONS FOR ALL AREAS OF NEW INSTALL OR DEMOLITION.


SHEET NOTES:	
1	DEMO ANALOG PHONE LOCATION AND CABLE TO SOURCE.
2	DEMO ABANDONED DATA DROP AND RACEWAY.
3	DEMO CRT TV AND MOUNT.
4	DEMO CUT/ABANDONED CABLE(S) AT THIS LOCATION.
5	DEMO CLOCK POWER SUPPLY AND SAFE OFF 120V POWER.
6	DEMO 66-BLOCK AND 25 PAIR FEEDER.
7	DEMO ABANDONED RACEWAY.
8	DEMO ABANDONED INTERCOM SPEAKER.
9	DEMO IDF CABINET, CCTV SWITCH, FIBER TO MDF AND 7 EA CAT CABLES TO FIELD.

1 - PIC. DETAIL RM 4 CLOSET DEMO

2 - PIC. DETAIL RM 14 CLOSET DEMO

3 - PIC. DETAIL RM 19 CLOSET DEMO

4 - PIC. DETAIL RM 27 CLOSET DEMO

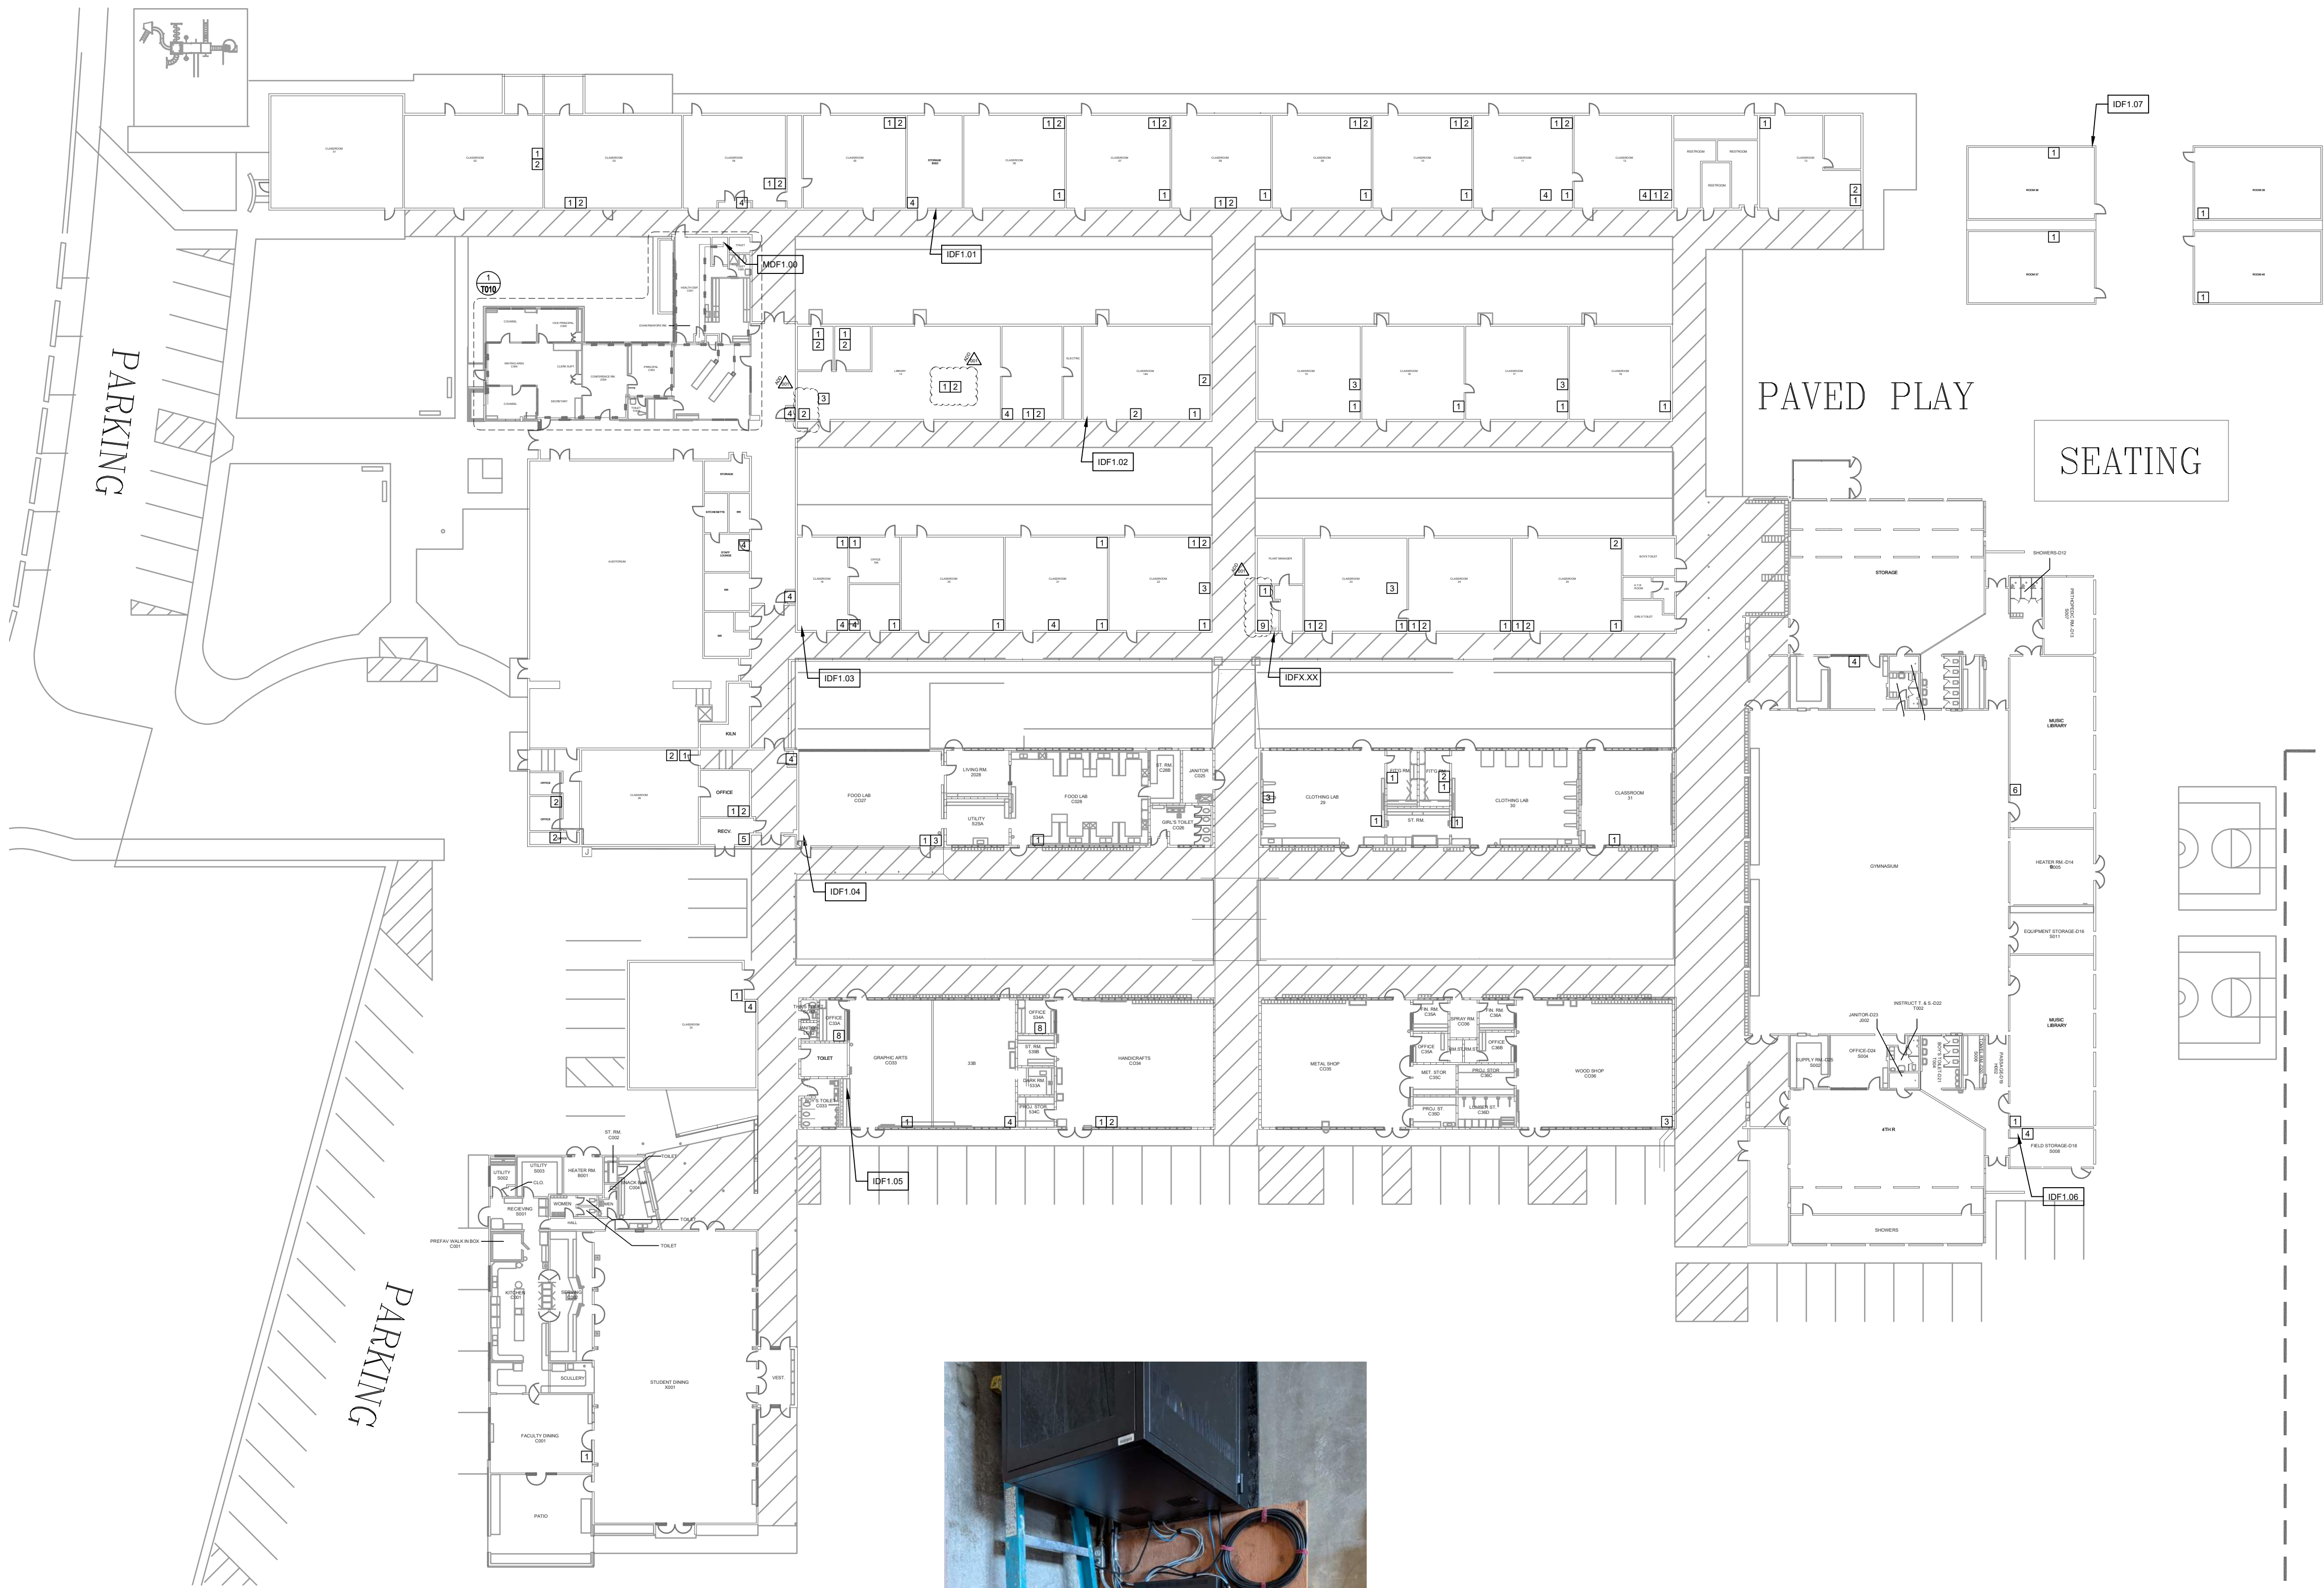

DEMO STATION CABLES
(APPROX 10)

DMARC BLOCK. PRESERVE.

DEMO ALL 66 BLOCKS EXCEPT
ORANGE DMARC BLOCK

BLACK FEEDERS TERMINATE
AT THE OTHER DEMO
LOCATIONS NOTATED ON
THIS SHEET


GREY FEEDERS END AT MDF
RACK (IN THIS ROOM)

5 - PICTURE DETAIL MDF DEMO



DEMO COPPER FEEDERS,
66 BLOCKS, AND
STATION CABLING.

6 - PICTURE DETAIL GYM STORAGE DEMO

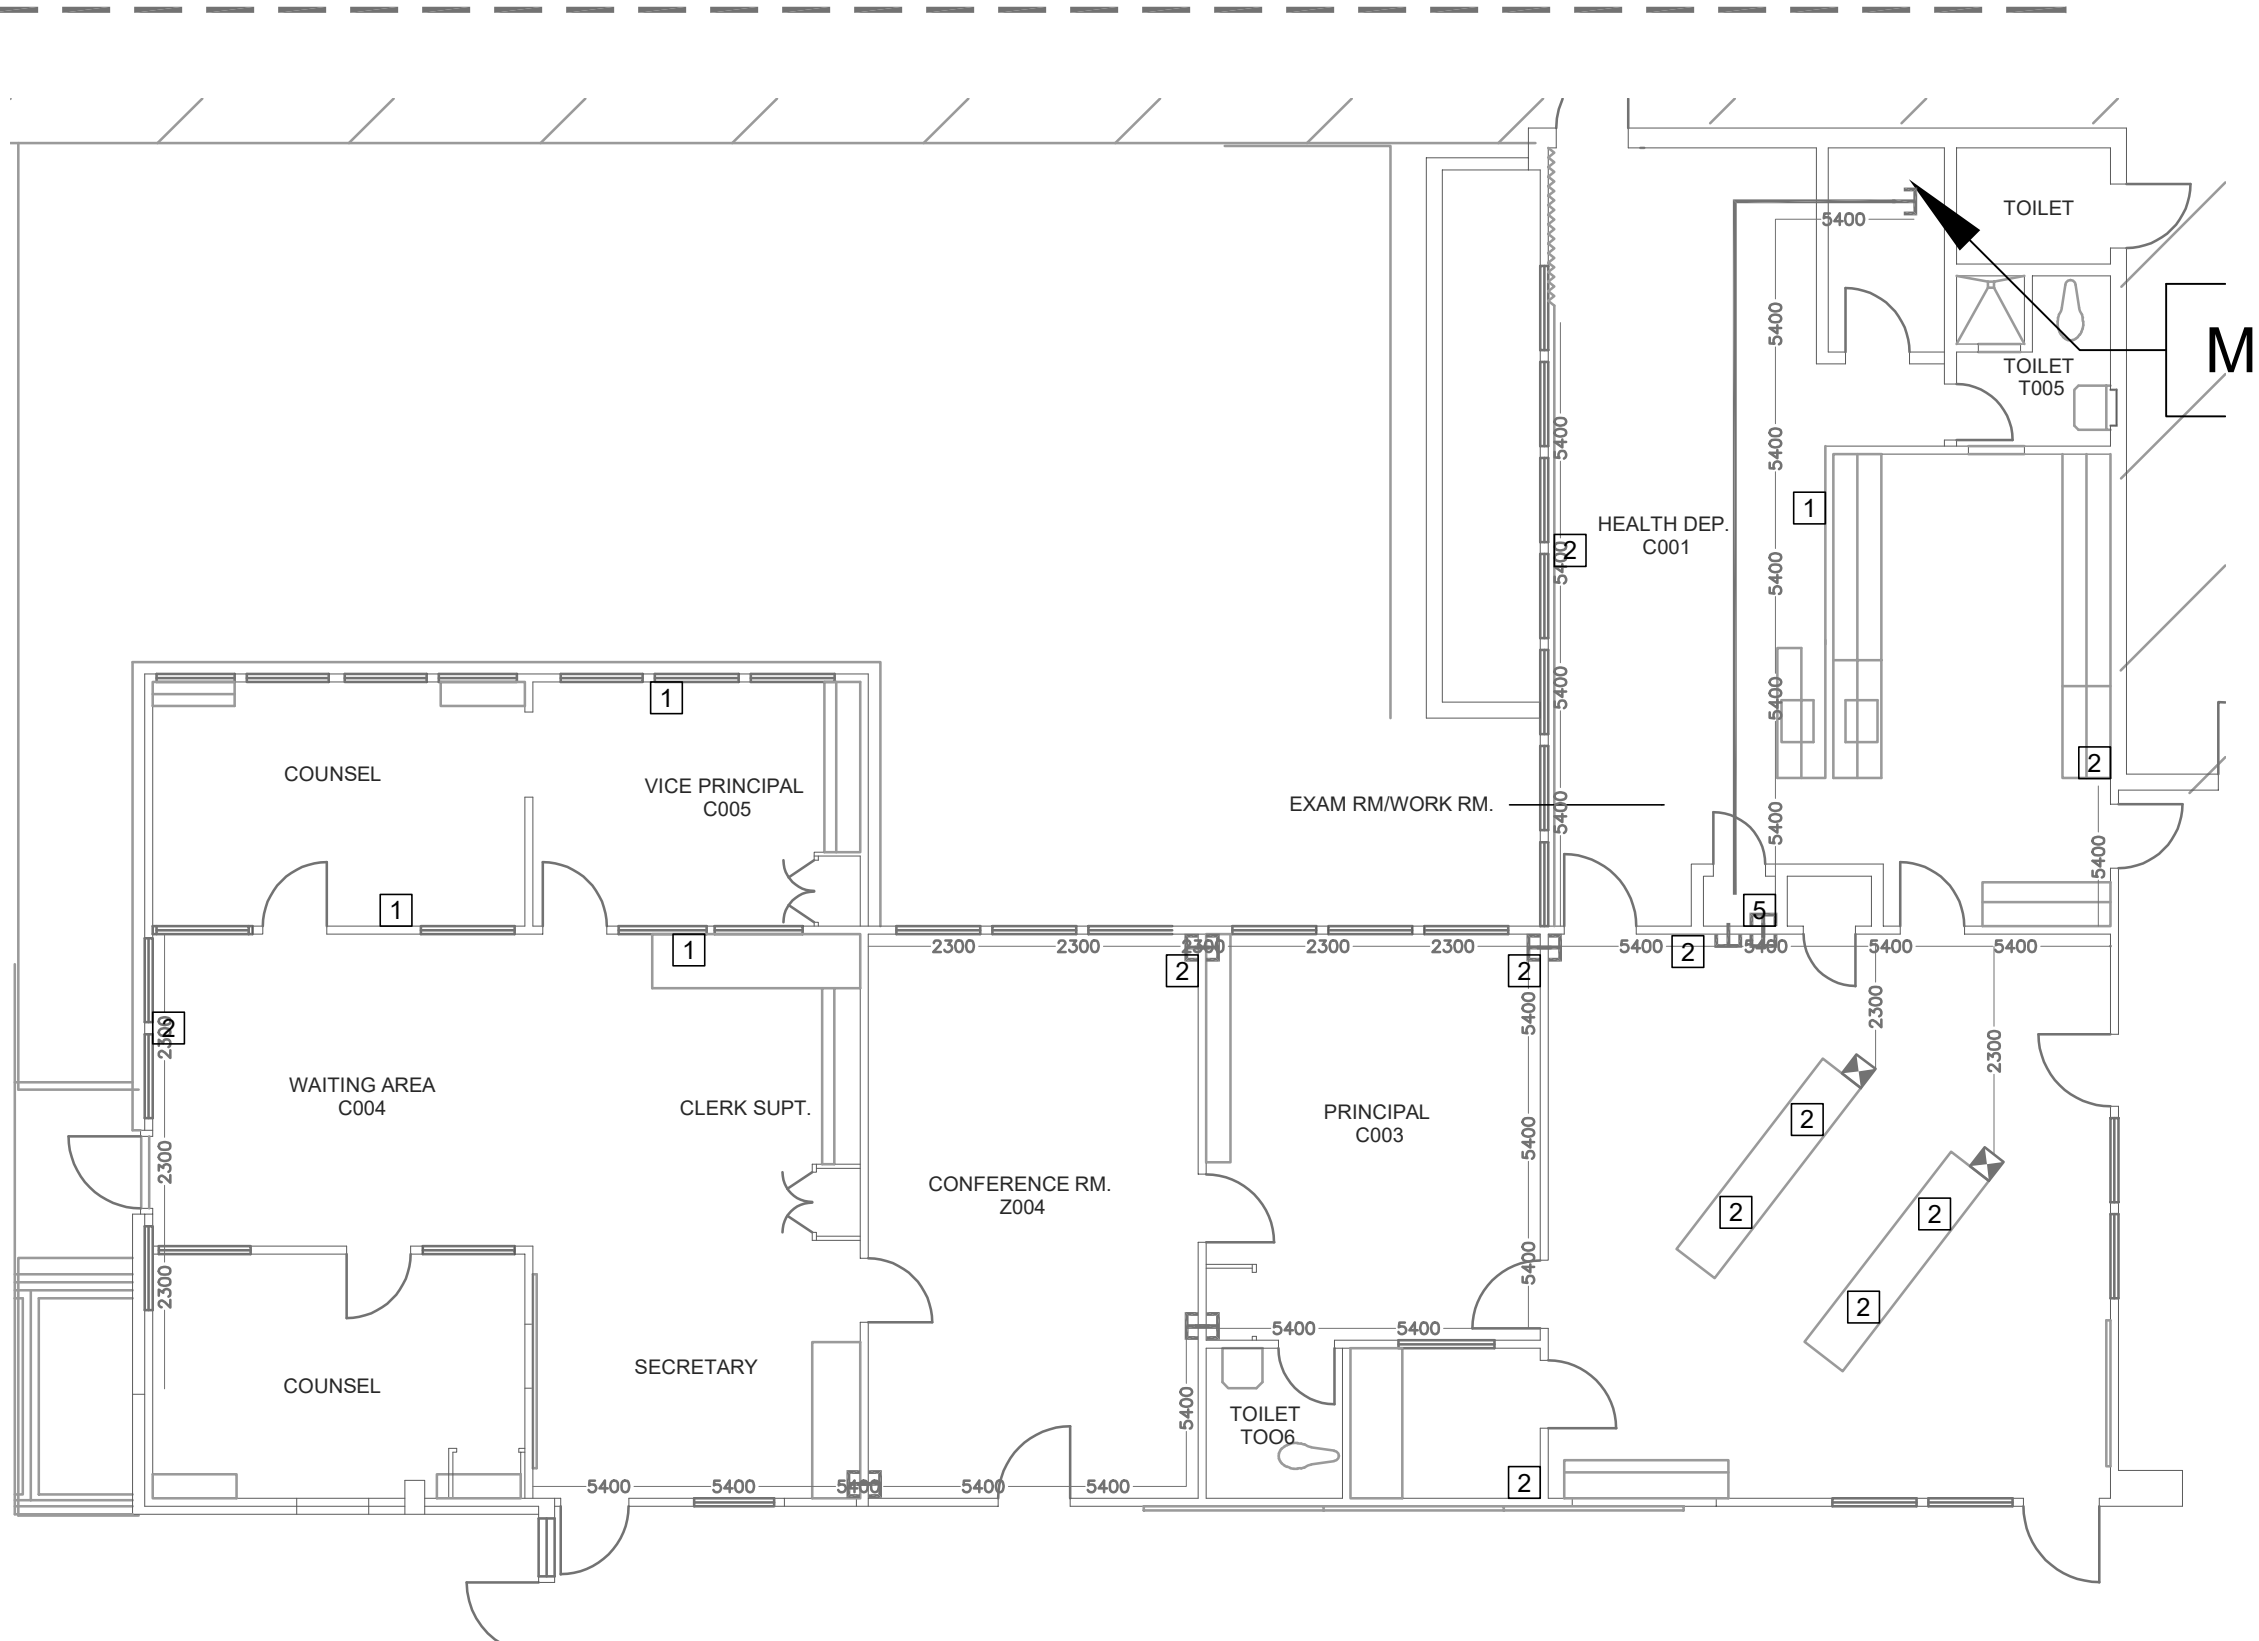

1 ENLARGED FLOOR PLAN - DEMO - ADMIN

CYBER SECURITY SITE PLAN - DEMO



KMM SERVICES, INC
TECHNOLOGY&FIRE LIFE SAFETY

5433 El Camino Ave. Suite 5
Carmichael, CA 95608
Office: (916) 359-4000 www.kmm-services.com

LICENSE STAMPS

Copyright © 2025
These drawings and specifications and the ideas, designs and arrangements represented thereby are and shall remain the property of KMM Services, Inc. and no part thereof shall be copied, reproduced, or used in connection with any other work or project other than the specific project for which they have been prepared and developed without the written consent of KMM Services, Inc. Visual contact with these drawings or specifications shall constitute conclusive evidence of these restrictions.

IF DRAWING IS NOT 30"x42" IT IS A REDUCED PRINT

SHEET REVISIONS

DELTA	DESCRIPTION	DATE
ADDENDUM		2026-08-10

SITE KEY PLAN

PROJECT
SACRAMENTO
CITY USD
LEONARDO DA VINCI K-8
NETWORK REPLACEMENT
4701 JOAQUIN WAY
SACRAMENTO, CA 95822

SHEET TITLE
CYBER SECURITY
SITE PLAN - DEMO


DRAWING STATUS
CONSTRUCTION DOCUMENTS

PROJECT NO:	-
BID PACKAGE:	426-LDV
DESIGNED BY:	RW/CS
CHECKED BY:	SD
ISSUE DATE:	2026-06-04
WORKING DATE:	2026-08-10

REVISION

SHEET

T010

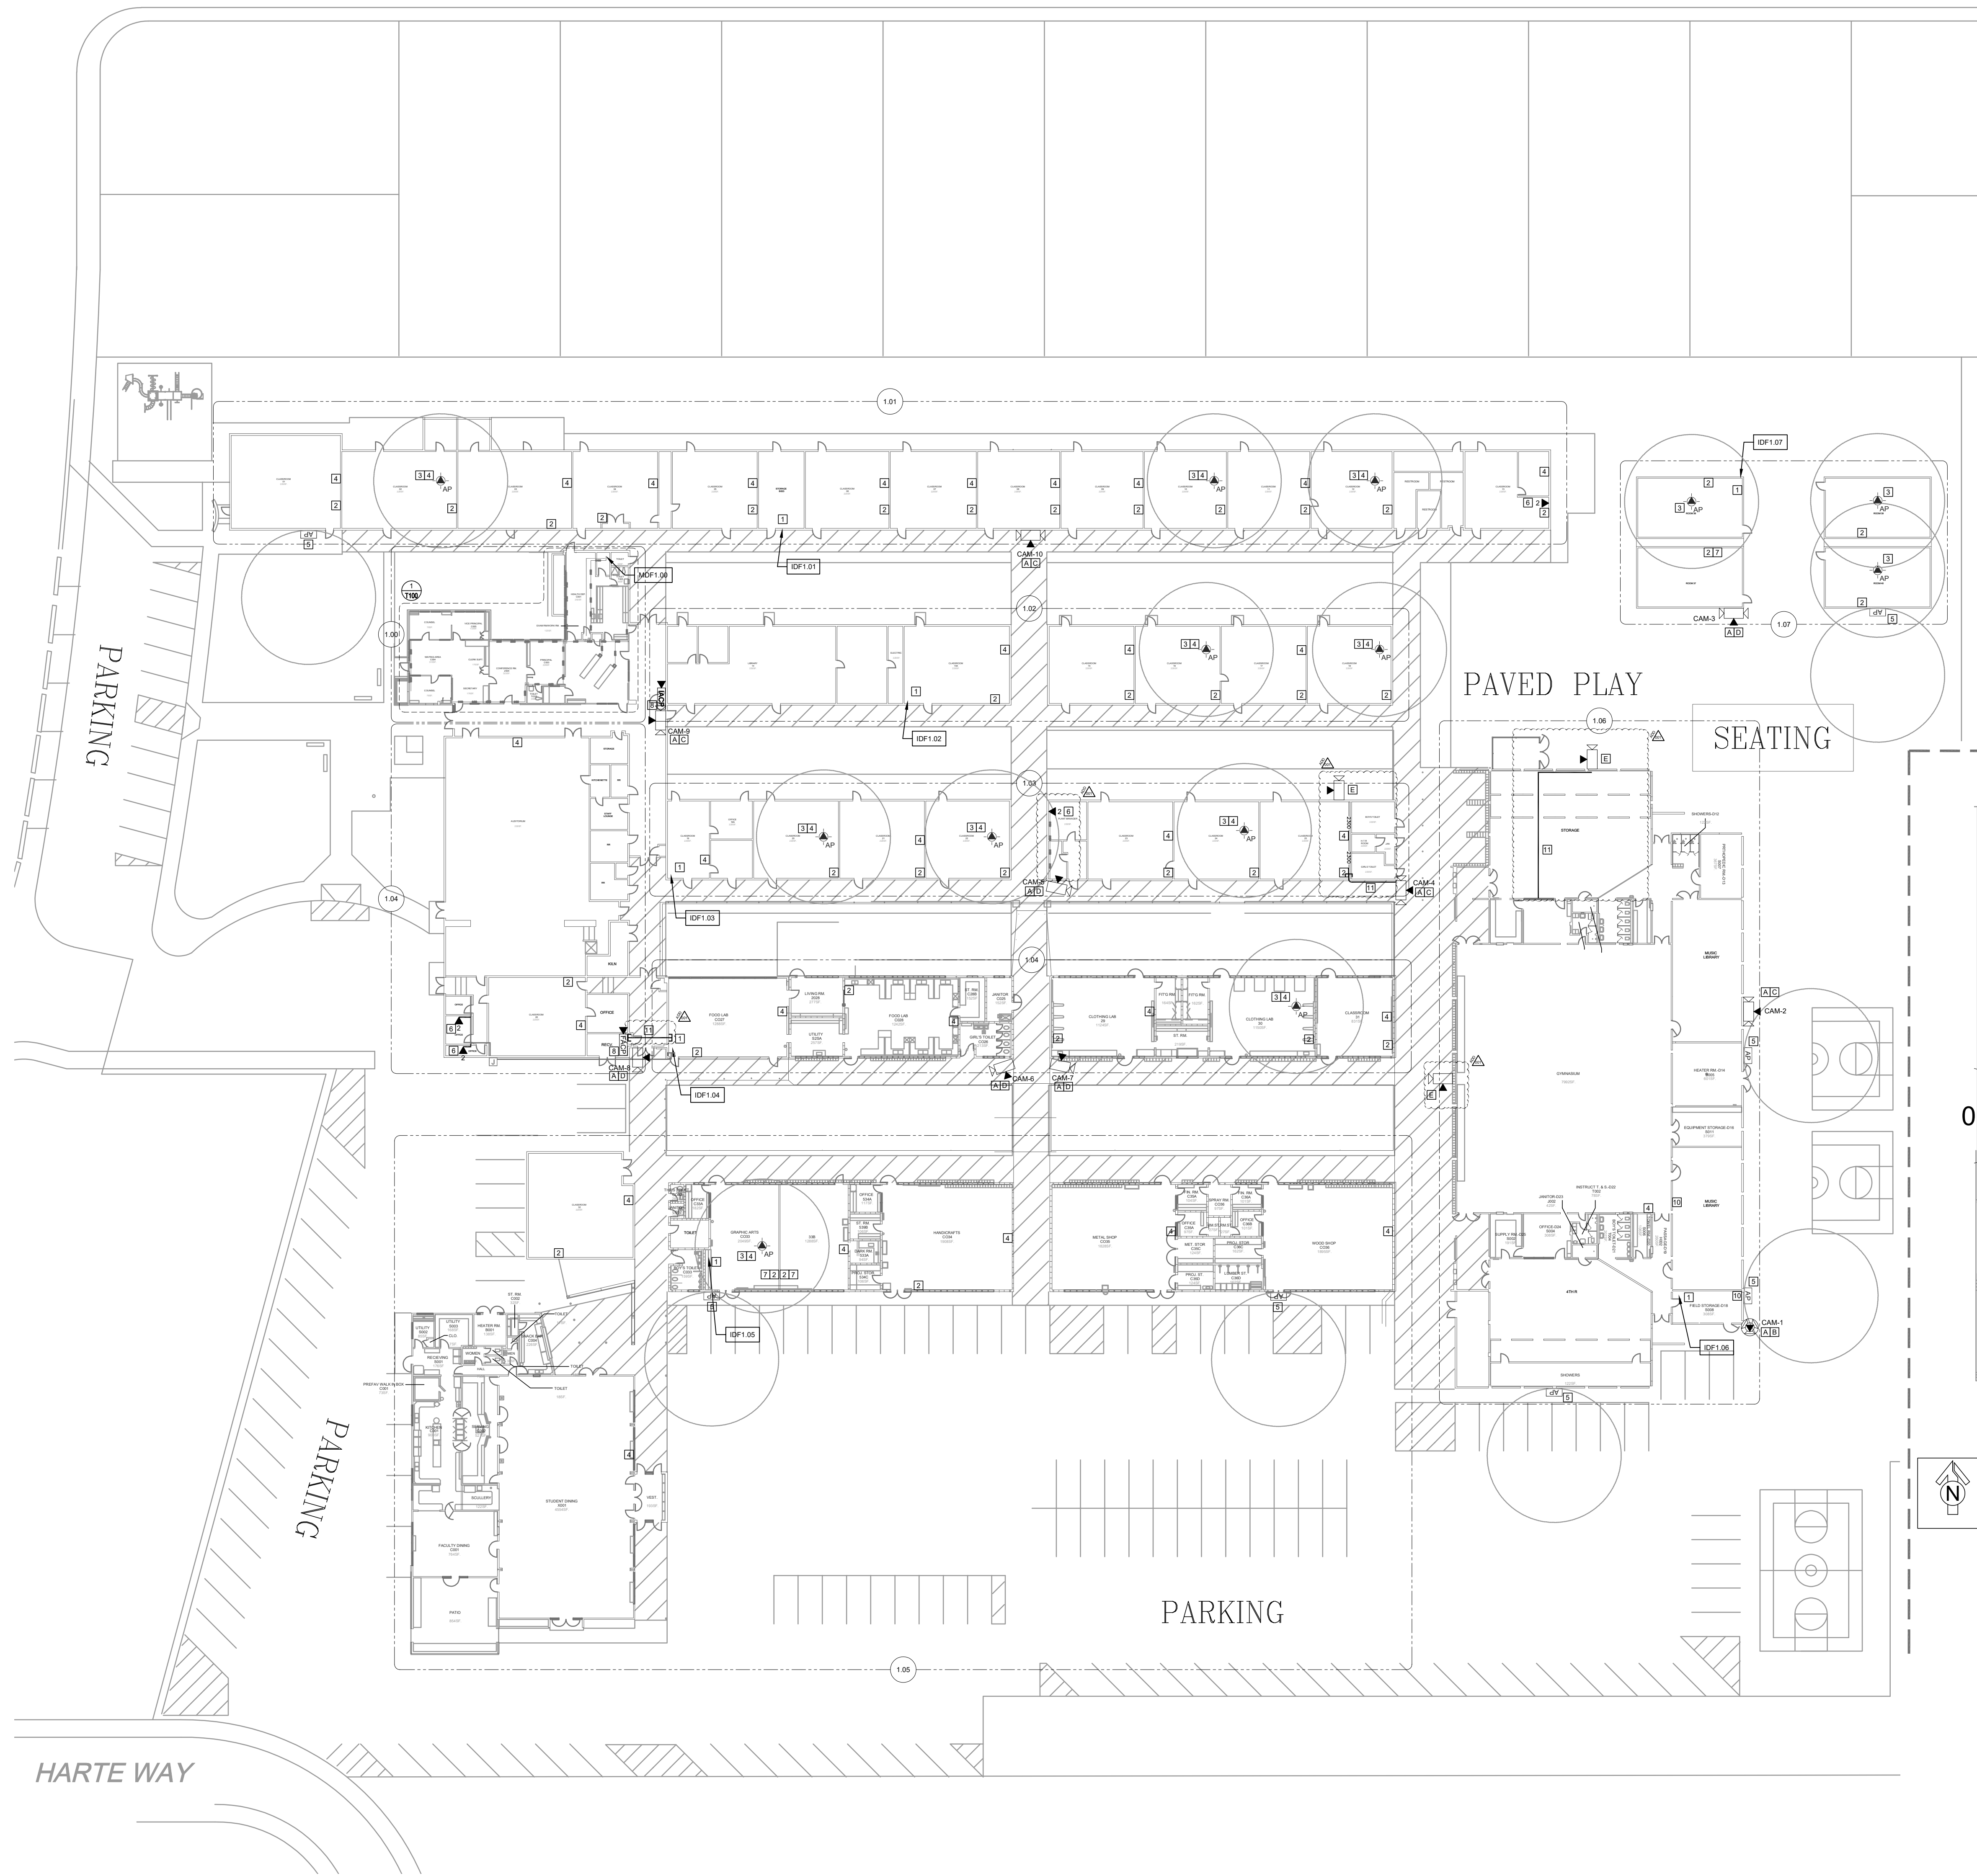

- GENERAL NOTES:
- NO STRUCTURAL BEAMS SHALL BE PENETRATED OR ALTERED.
 - ALL EQUIPMENT AND MATERIALS ARE CONTRACTOR FURNISHED, INSTALLED, AND CONFIGURED, UNO.
 - CONTRACTOR SHALL TOUCH UP PAINT TO MATCH EXISTING CONDITIONS FOR ALL AREAS OF NEW INSTALL OR DEMOLITION.

- SHEET NOTES:
- REWORK MDF/IDF RACK PER ELEVATION. SEE T400/T401.
 - PROVIDE (N) WALL MOUNT KIT CISCO P/N DP-8800-WMK AND MOUNT (E) PHONE AT WALL DATA LOCATION.
 - INSTALL (N) OWNER-FURNISHED AP AT (E) AP LOCATION.
 - PROVIDE (N) RIGHT ANGLE WALL MOUNT AT (E) AP, OBERON P/N 1006-COAP9136.
 - AT EXTERIOR AP LOCATION, REWORK (E) DATA DROP AND PROVIDE REQUIRED COMPONENTS PER DETAIL 27800. INSTALL (N) OWNER-FURNISHED EXTERIOR AP.
 - PROVIDE (N) CAT6A DATA DROP, QTY INDICATED.
 - PROVIDE (N) ORTRONICS DATA PLATE AT WALL PHONE LOCATION.
 - AT IACP/FACP, PROVIDE (N) 1 EA. CAT6A DATA DROP AND (N) 2 EA. 4-PAIR COPPER FEEDERS FOR ANALOG PHONE AND RELAY CLOSURE. CABLE TO MDF VIA (E) PATHWAY.
 - AFTER DEMO OF OLD DATA CABLES, REWORK (E) 2" CONDUIT INTO (N) J-BOX TO ELIMINATE EXPOSED CABLING AT THIS LOCATION.
 - RE-SECURE (E) WIREMOLD FALLING OFF WALL.
 - PROVIDE (N) 1 EA. 3/4" CONDUITS.
 - INSTALL (N) OFCI EXTERIOR NETWORK SECURITY CAMERA. PROVIDE 1 EA. (N) CAT6A DATA DROP.
 - MOUNT CAMERA ON CORNER OF BUILDING.
 - MOUNT CAMERA ON WALL.
 - MOUNT CAMERA ON WALL AT BUILDING CORNER.
 - PROVIDE (N) CAT6A DATA DROP AT (E) CCTV CAMERA, CABLED TO NEAREST IDF. PROVIDE (N) PATHWAY AS NOTED. RE-SEAL CONNECTION AT CAMERA WITH WATERPROOF TAPE PER MFG SPECIFICATIONS.



KMM SERVICES, INC
TECHNOLOGY & FIRE LIFE SAFETY

5433 El Camino Ave., Suite 5
Carmichael, CA 95608
Office: (916) 359-4000 www.kmm-services.com

LICENSE STAMPS

Copyright © 2025
These drawings and specifications and the ideas, designs and arrangements represented thereby are and shall remain the property of KMM Services, Inc. and no part thereof shall be copied, disclosed to others, or used in connection with any other work or project other than the specific project for which they have been prepared and developed without the written consent of KMM Services, Inc. Visual contact with these drawings or specifications shall constitute conclusive evidence of these restrictions.

IF DRAWING IS NOT 30"x42" IT IS A REDUCED PRINT

SHEET REVISIONS

DELTA	DESCRIPTION	DATE
ADDENDUM		2026-08-10

SITE KEY PLAN

PROJECT
SACRAMENTO
CITY USD
LEONARDO DA VINCI K-8
NETWORK REPLACEMENT
4701 JOAQUIN WAY
SACRAMENTO, CA 95822


SHEET TITLE
CYBER SECURITY
SITE PLAN - NEW

DRAWING STATUS
CONSTRUCTION DOCUMENTS

PROJECT NO:	-
BID PACKAGE:	426-LDV
DESIGNED BY:	RWCS
CHECKED BY:	SD
ISSUE DATE:	2026-06-04
WORKING DATE:	2026-08-10


REVISION

SHEET
T100

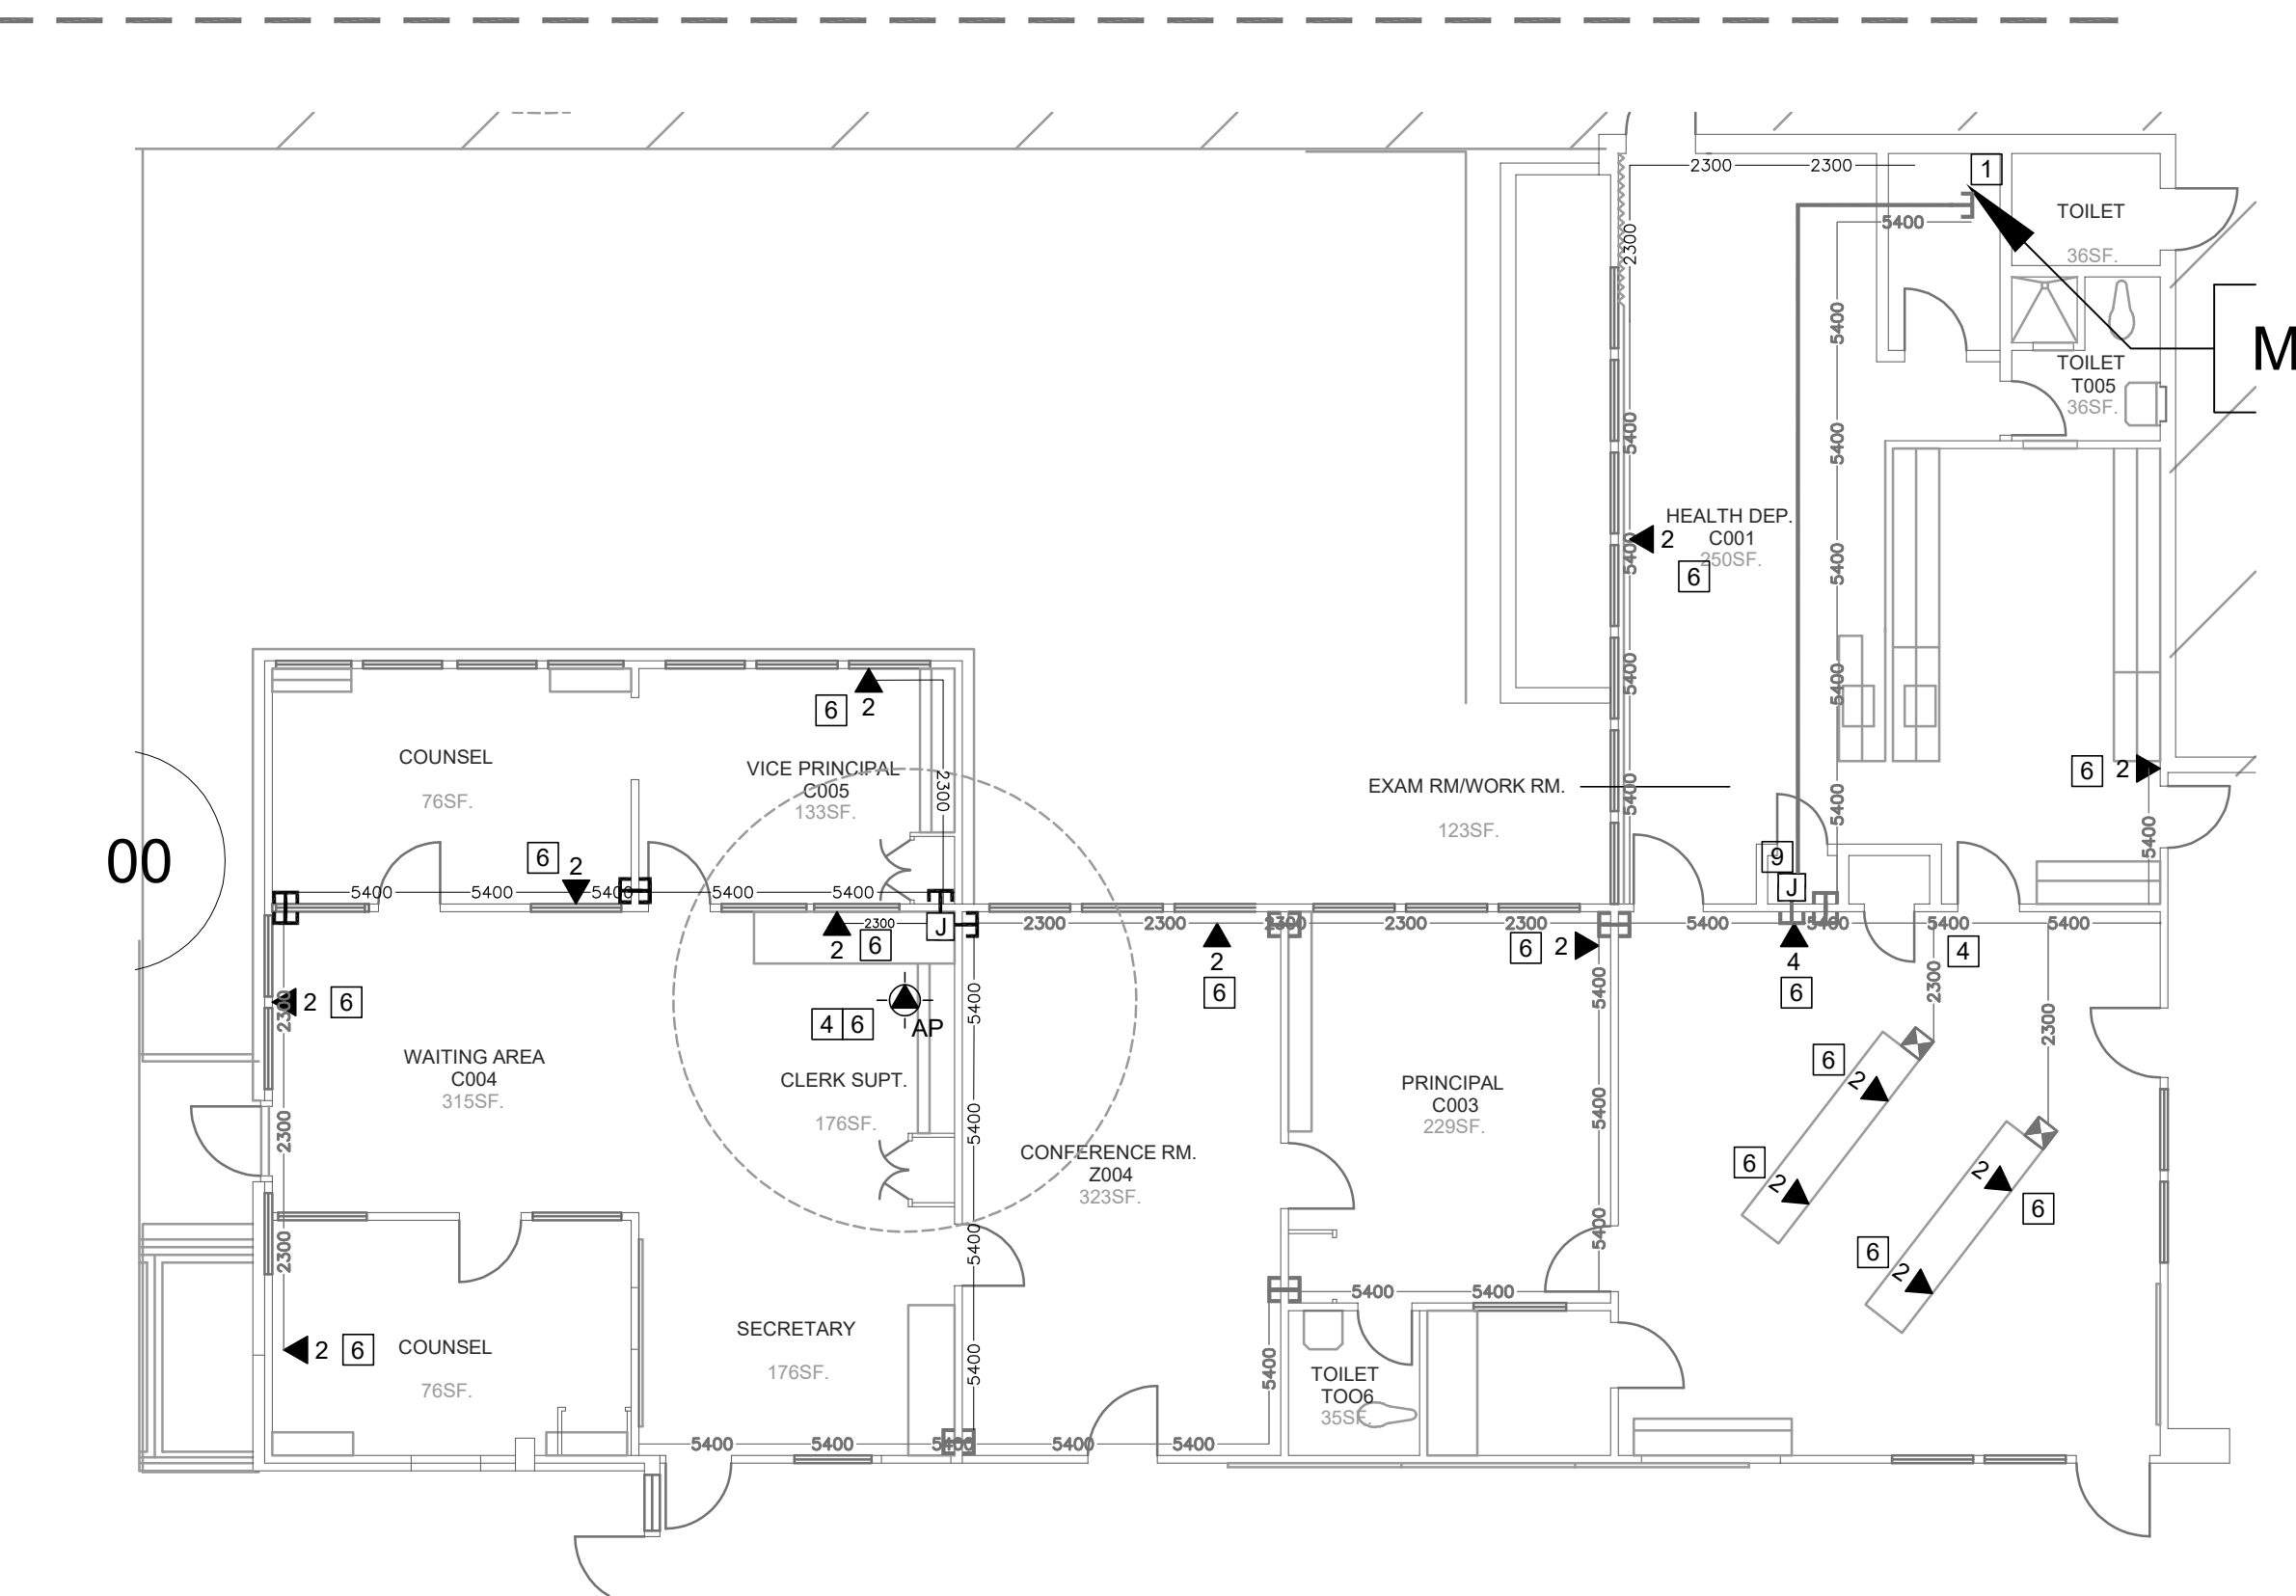

1 ENLARGED FLOOR PLAN - NEW - ADMIN

SCALE: 1/8"=1'-0"

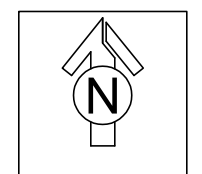

CYBER SECURITY SITE PLAN - NEW

SCALE: 1"=30'-0"

