

ADDENDUM #6

Date: October 20, 2026

Project: New Locker Room Facility and Renovations to the
Existing Concession and Tennis Facilities Project at the
Merrillville High School
276 E 68th Place
Merrillville, Indiana 46410

Architect's Project #26027

To: Prospective Bidders

This addendum forms a part of the Bid Documents and modifies the original Bid Documents dated October 2, 2026 as noted below. Acknowledge receipt of this addendum in the space on the Bid Form. Failure to do so may subject bidder to disqualification.

GENERAL

1. Contractors are to Provide Equipment Listed below:
 - i. Ice Machine: Manitowoc Indigo NXT iT0500 Ice Cube Machine, D-400
 - ii. Exam Chairs: Brewer- Access Fixed Height Exam Table – Model 5000

DRAWINGS

2. See attached Revised Drawing Sheet P1.1.0-A – Master Plumbing Plan – Dated 10/16/2026 - This drawing is being reissued in its entirety.
3. See attached Revised Drawing Sheet P1.1.1-A – Partial Plumbing Plan – Area A – Dated 10/16/2026 - This drawing is being reissued in its entirety.
4. See attached Revised Drawing Sheet P1.1.2-A – Partial Plumbing Plan – Area B – Dated 10/16/2026 - This drawing is being reissued in its entirety.
5. See attached Revised Drawing Sheet M1.1.0-A – Mechanical HVAC Floor Plan – Area A – This plan shows clouded and tagged revisions dated 10/20/2026.
6. See attached Revised Drawing Sheet A7.1.0-B – Interior Elevation & Room Finish schedule - This plan shows clouded and tagged revisions dated 10/20/2026.
7. See attached Revised Drawing Sheet M1.1.0-B – Mechanical HVAC Floor Plan – This plan shows clouded and tagged revisions dated 10/20/2026.
8. See attached Revised Drawing Sheet M2.1.0-A – Mechanical Schedule – This plan shows clouded and tagged revisions dated 10/20/2026.

Attached to Addendum #6

- Revised Drawing Sheet P1.1.0-A – Master Plumbing Plan
- Revised Drawing Sheet P1.1.1-A – Partial Plumbing Plan – Area A
- Revised Drawing Sheet P1.1.2-A – Partial Plumbing Plan – Area B
- Revised Drawing Sheet M1.1.0-A – Mechanical HVAC Floor Plan – Area A

- Revised Drawing Sheet A7.1.0-B – Interior Elevation & Room Finish schedule
- Revised Drawing Sheet M1.1.0-B – Mechanical HVAC Floor Plan
- Revised Drawing Sheet M2.1.0-A – Mechanical Schedule


END OF ADDENDUM #6

X:\Merrillville Schools\26027 New Locker Facility & Renovation to Tennis Bldg\Drawings\Z_Blg A_Locker Room\p100 plumbing.dwg

CONNECT NEW 4" SANITARY PIPE
(COORDINATE WITH SITE CIVIL DRWGS.)

FCO

NEW 3" WATER SERVICE LINE
(COORDINATE WITH CIVIL DRAWINGS.)

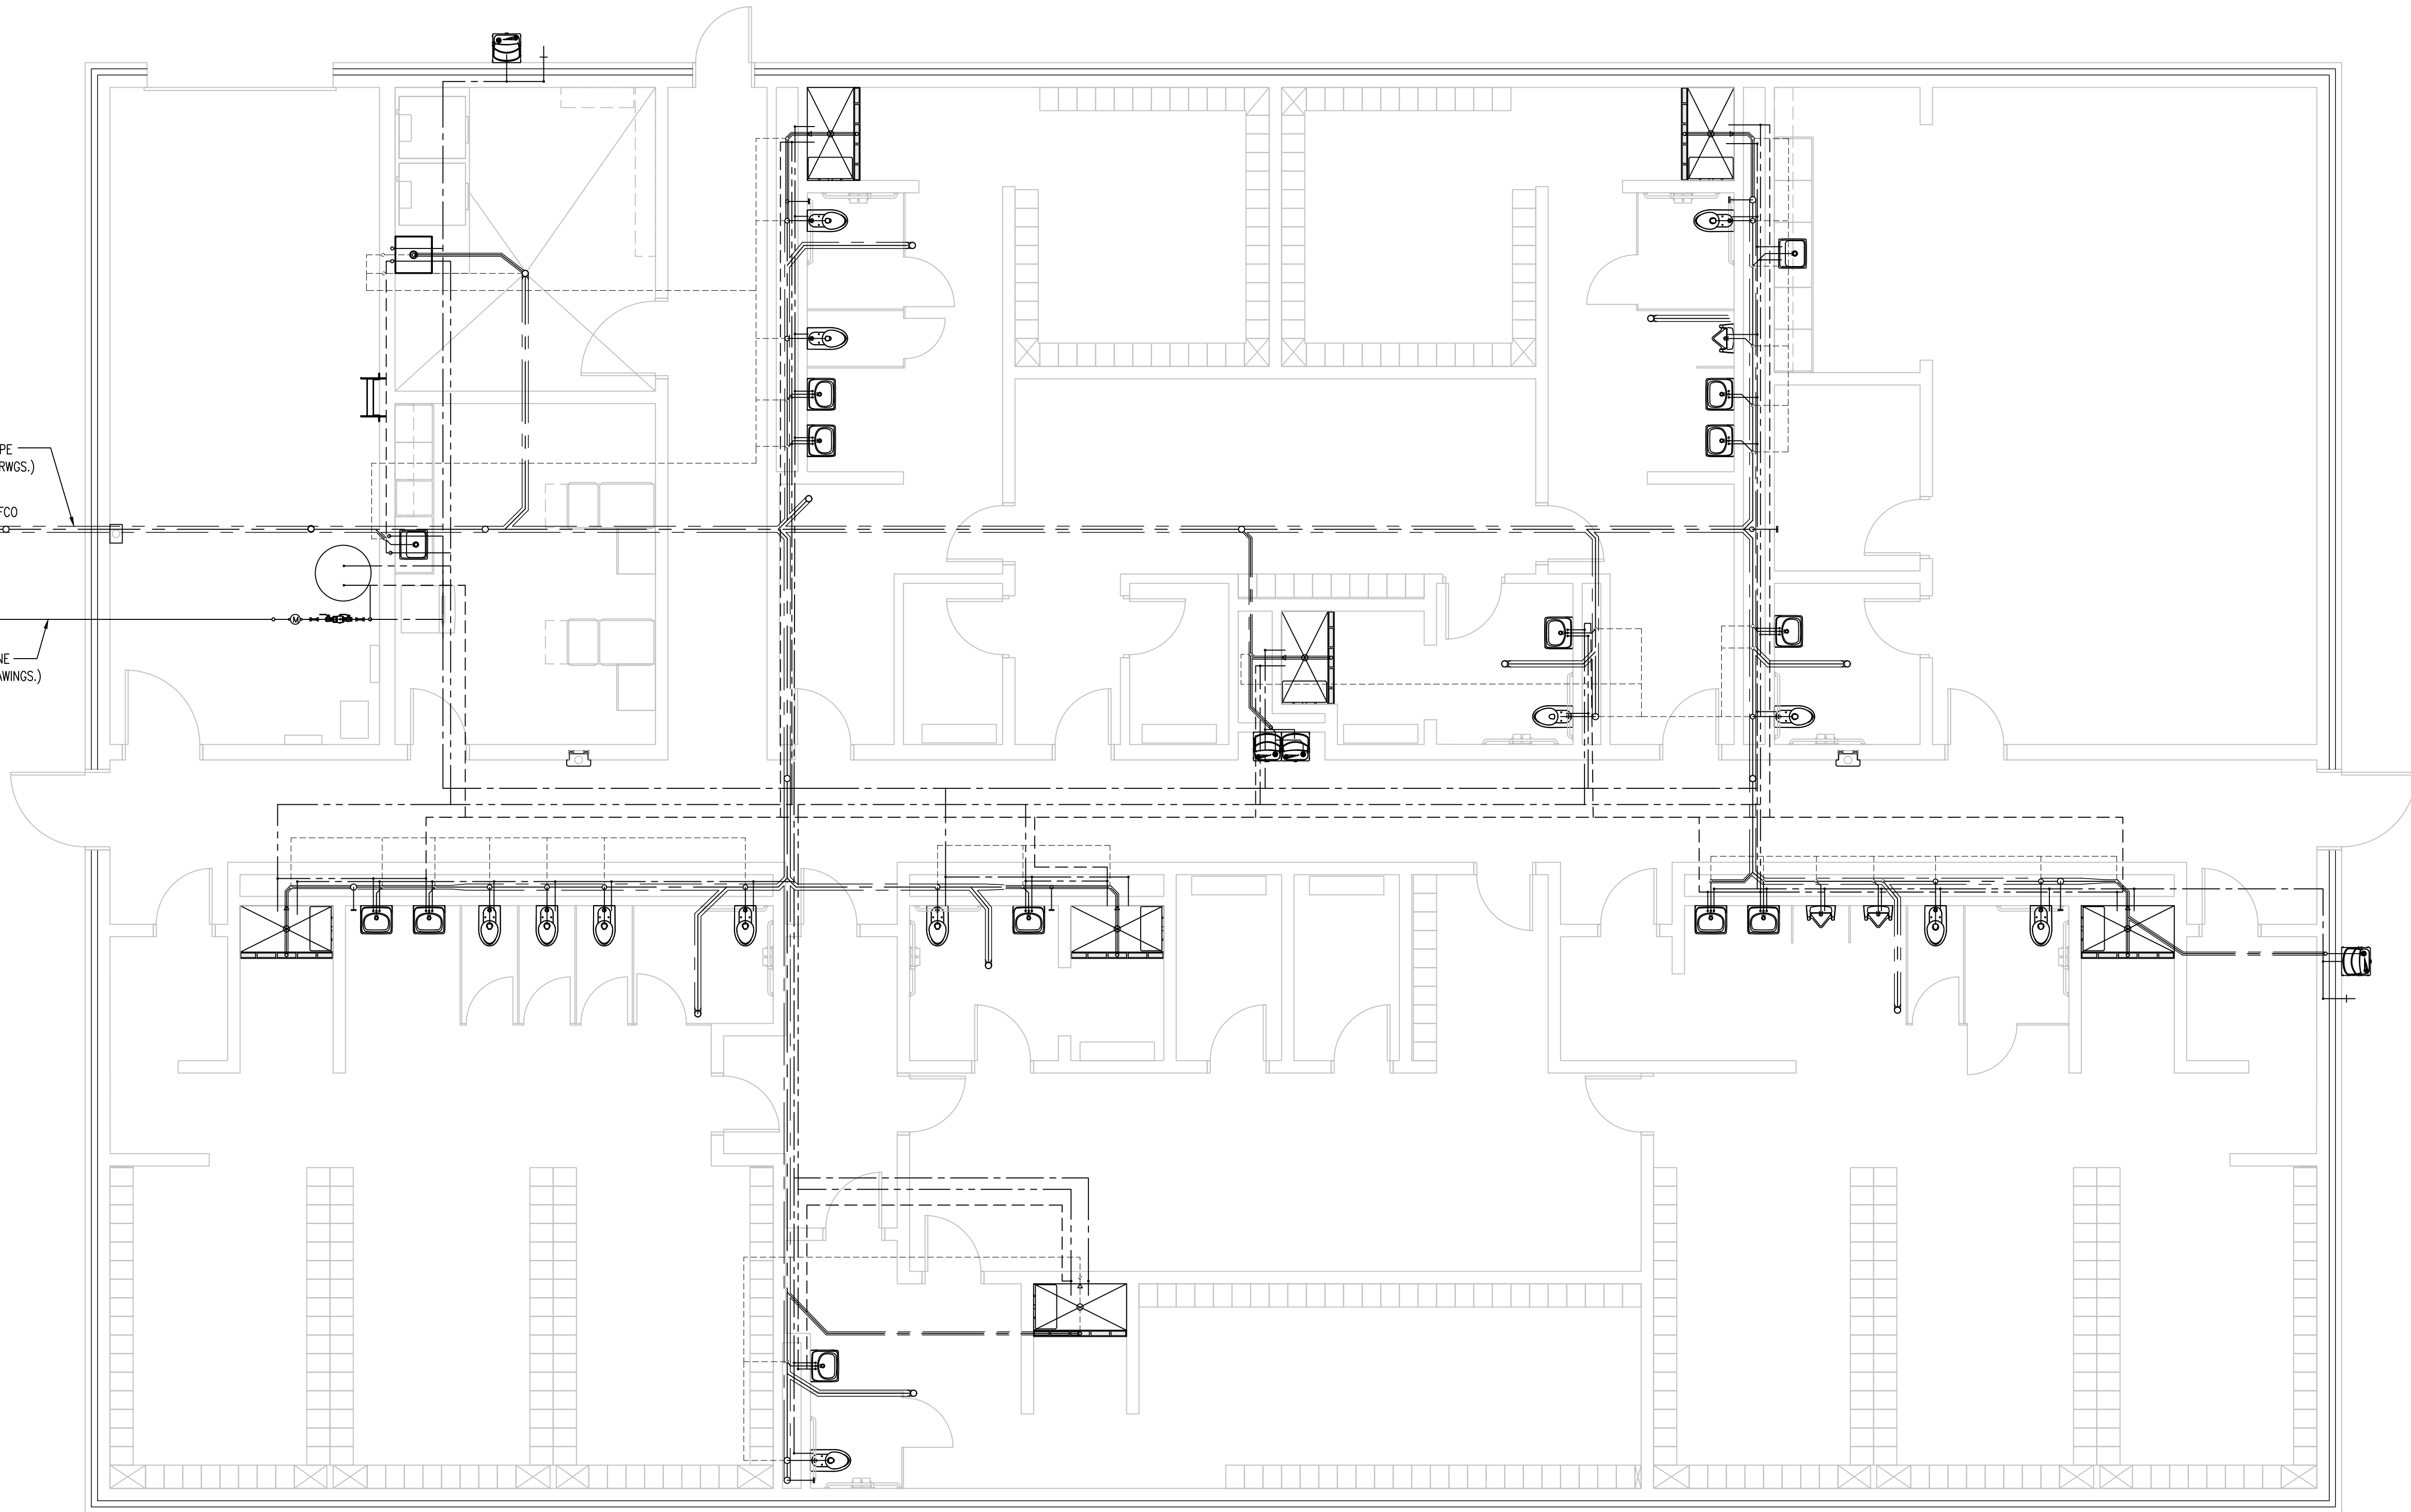

MASTER PLUMBING PLAN

SCALE: 3/16" = 1'-0"



SHEET ISSUED IN ENTIRETY



DATE
10-02-2026

10-20-2026 - ADD#6

NEW LOCKER ROOM FACILITY & RENOVATIONS TO
THE EXISTING CONCESSION & TENNIS FACILITY AT
MERRILLVILLE HIGH SCHOOL
276 E. 68TH PLACE
MERRILLVILLE, IN 46410

CSK ARCHITECTS, P.C.


6919 W. LINCOLN HIGHWAY
219-322-5950

CROWN POINT, IN 46307
www.cskarchitects.com

26027

SHEET
P
1.1.0-A

X:\Merrillville Schools\26027 New Locker Facility & Renovation to Tennis Bldg\Drawings\Z_Blg A_Locker Room\p100 plumbing.dwg

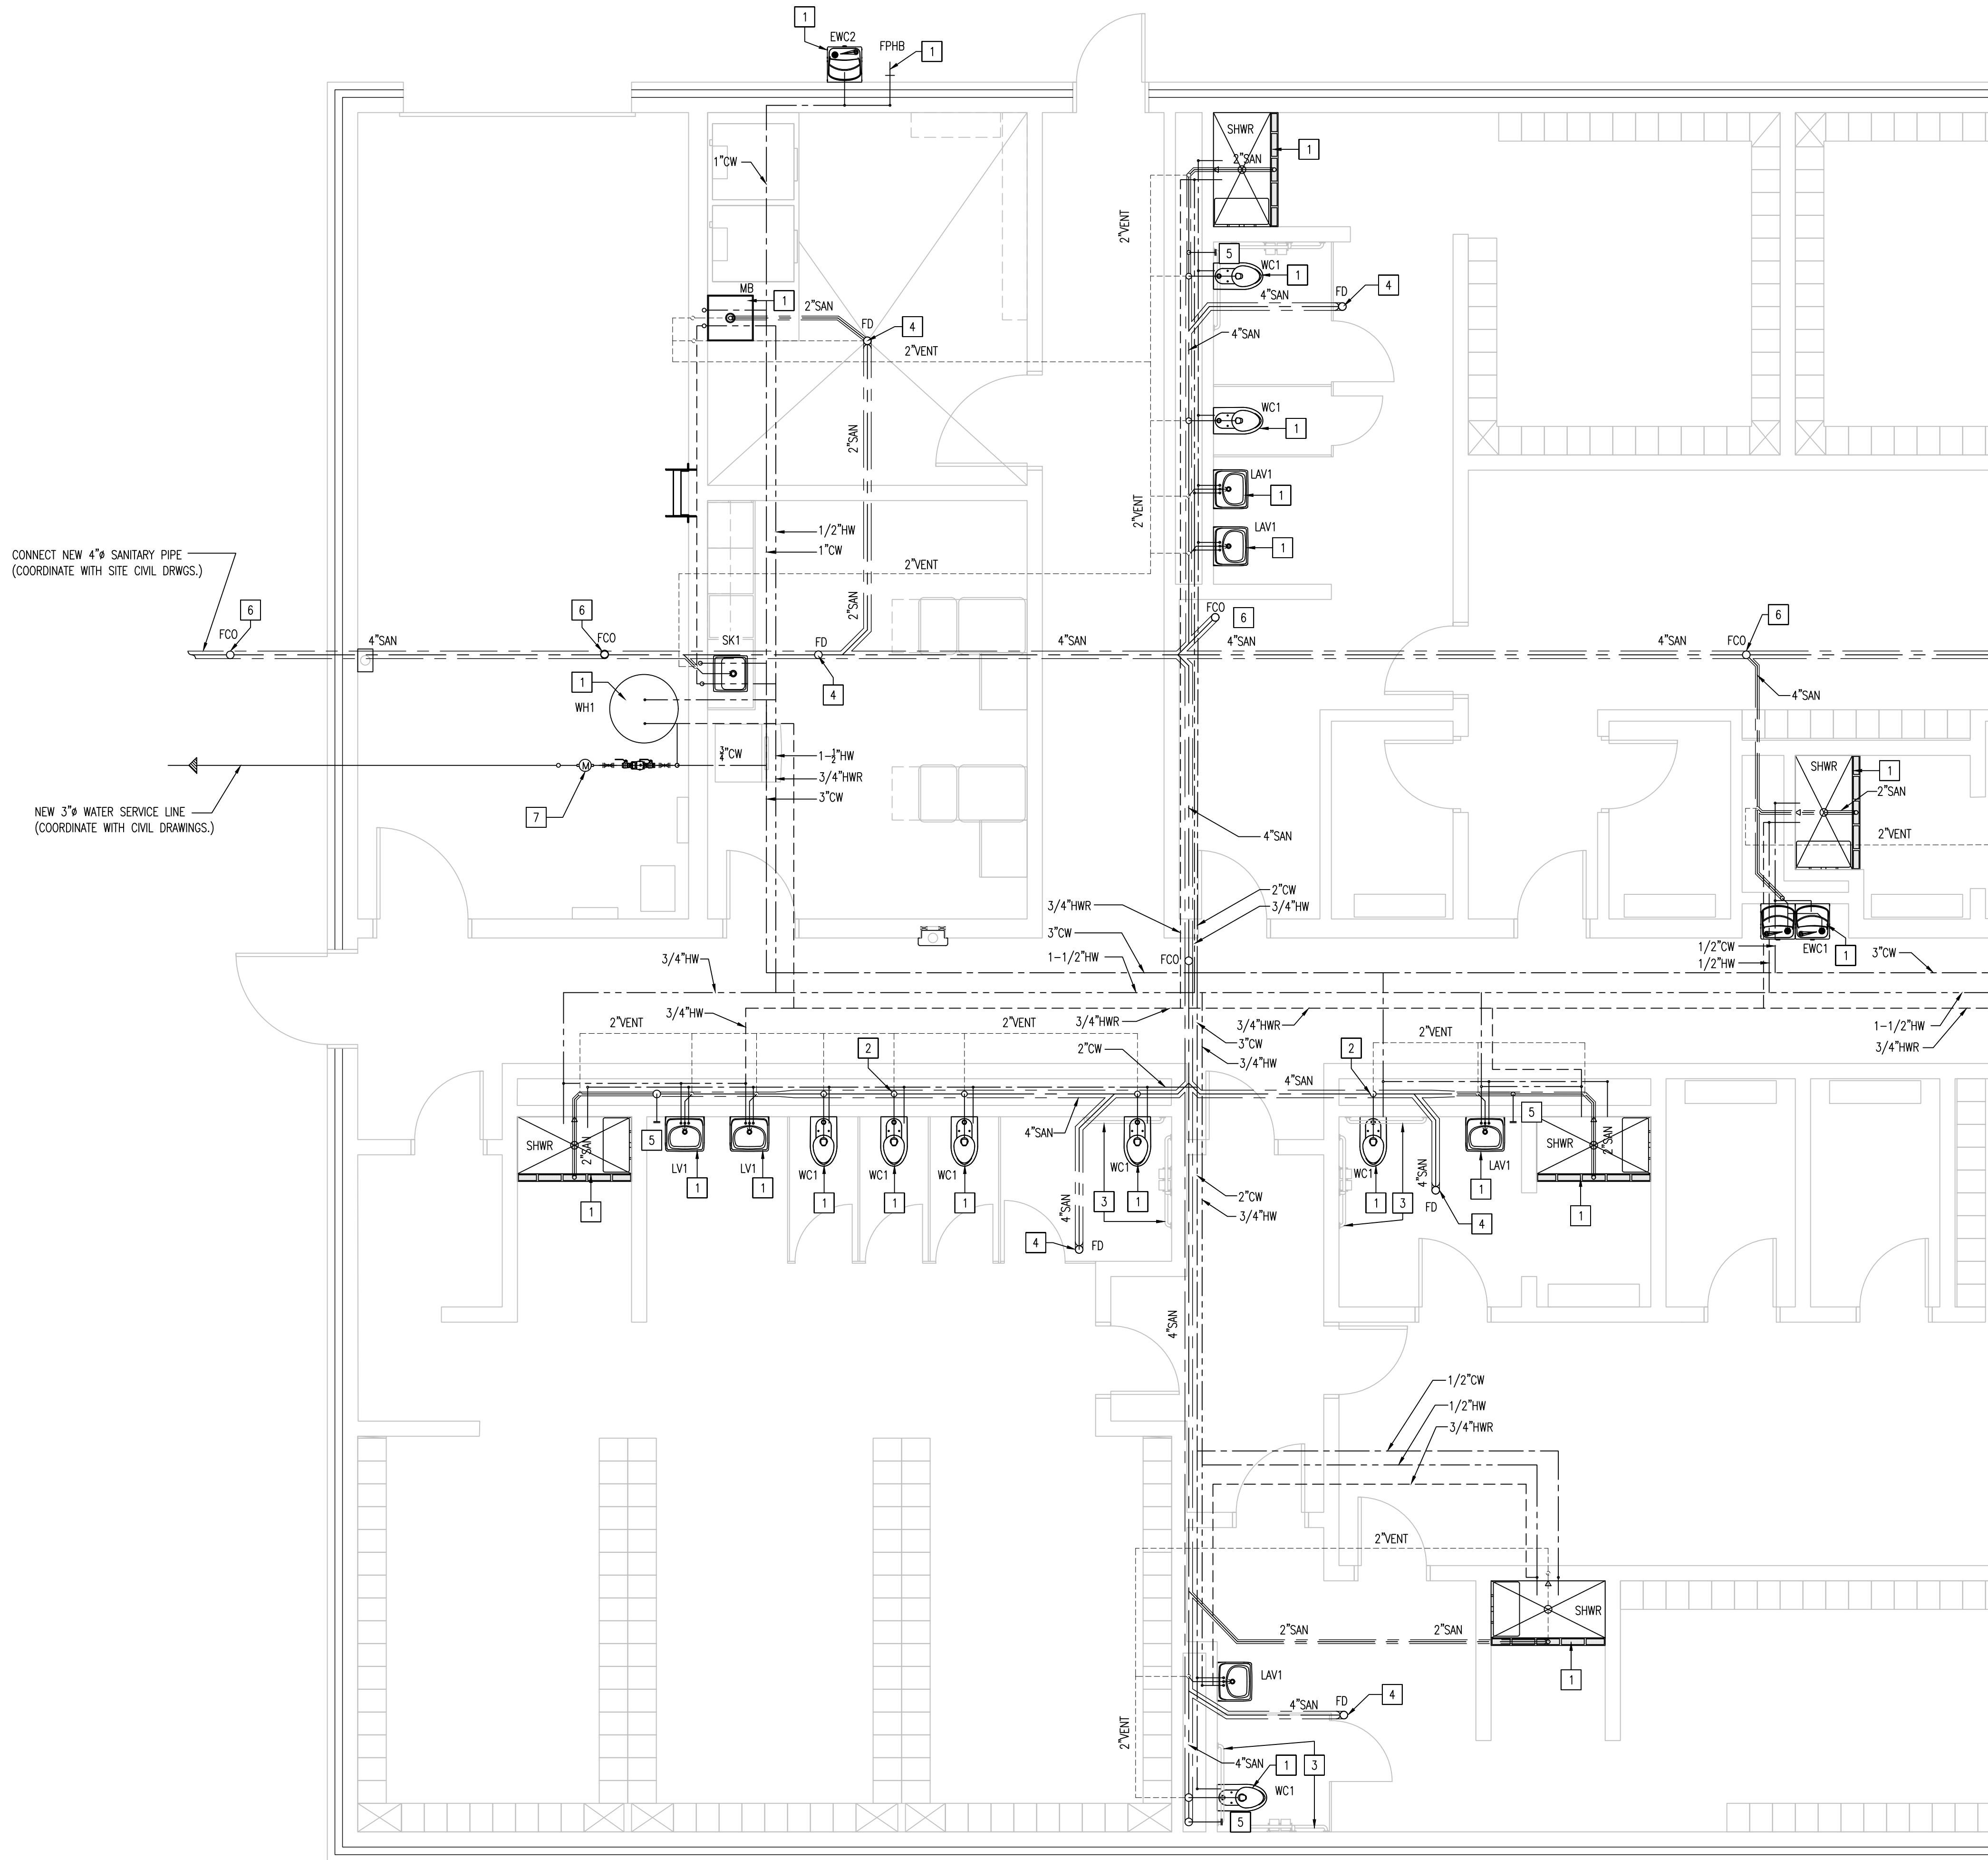

PLUMBING PLAN GENERAL NOTES:

1. FIELD VERIFY ALL DIMENSIONS & CONDITIONS PRIOR TO CONSTRUCTION.
2. ALL WORK, NEW PIPING SIZE AND MATERIAL SHALL BE IN FULL ACCORDANCE WITH THE PLUMBING CODE.
3. ALL PLUMBING FIXTURE VENTS TO TERMINATE A MINIMUM OF 12 INCHES FROM ANY VERTICAL SURFACE AND 10'-00" FROM OR 3'-00" ABOVE ANY MECHANICAL EQUIPMENT OUTSIDE AIR INTAKE.
4. EXTEND AND FLASH ALL PLUMBING VENTS AS REQUIRED.
5. FIRE CAULK AT ALL PIPE OPENINGS THRU FLOORS, WALLS AND ROOFS.
6. INSULATE COLD WATER LINES AT UNCONDITIONED SPACE.
7. PROVIDE PVC P-TRAPS FOR DRAIN LINES OF ALL NEW SINKS.
8. PIPING LAYOUT IS SCHEMATIC ONLY, EXACT ROUTING AND INSTALLATION OF PIPES TO BE COORDINATED WITH THE BUILDING STRUCTURE AND THE WORK OF OTHER CONTRACTORS. NO WATER OR DRAIN LINES ARE PERMITTED TO BE INSTALLED OVER OR UNDER ELECTRICAL PANEL.

PLUMBING PLAN KEYNOTES:

1. NEW PLUMBING FIXTURE CONNECT VIA NEW WATER SUPPLY LINES AND SANITARY SYSTEM. REFER TO PLUMBING FIXTURE SCHEDULE THIS SHEET.
2. NEW 4" DIA. PVC VENT THRU ROOF (VTR) - PROVIDE ROOF FLASHING AS REQUIRED.
3. NEW ADA GRAB BARS - REFER TO INTERIOR ELEVATIONS
4. NEW FLOOR DRAIN-REFER TO SPECIFICATION.
5. NEW WALL CLEANOUT- REFER TO SPECIFICATION.
6. NEW FLOOR CLEANOUT - REFER TO SPECIFICATION.
7. NEW 3" DOMESTIC WATER METER W/STRAINER, VALVES, BYPASS, AND BACKFLOW PREVENTER PROVIDED AND INSTALLED BY LOCAL WATER COMPANY.

PLUMBING PIPE LEGEND

COLD WATER SUPPLY PIPING	CW
HOT WATER SUPPLY PIPING	HW
HOT WATER RETURN PIPING	HWR
SANITARY SEWER PIPING	SAN
UNDER FLOOR SANITARY SEWER PIPING	SAN
PVC VENT PIPING	VENT
CTC	CONNECT TO EXISTING


PARTIAL PLUMBING PLAN

AREA A

SCALE: 1/4" = 1'-0"



SHEET ISSUED IN ENTIRETY

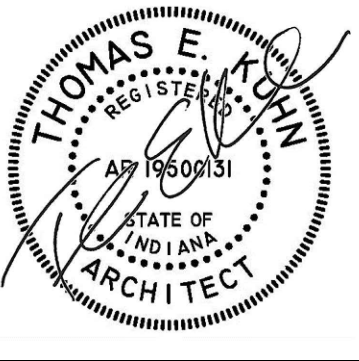

DATE
10-02-2026
10-07-2026
10-20-2026 - ADD#6

NEW LOCKER ROOM FACILITY & RENOVATIONS TO
THE EXISTING CONCESSION & TENNIS FACILITY AT
MERRILLVILLE HIGH SCHOOL
276 E. 68TH PLACE
MERRILLVILLE, IN 46410

CSK ARCHITECTS, P.C.


CROWN POINT, IN 46307
www.cskarchitects.com

6919 W. LINCOLN HIGHWAY
219-322-5950

26027

SHEET
P
1.1.1-A

X:\Merrillville Schools\26027 New Locker Facility & Renovation to Tennis Bldg\Drawings\Z_Blg A_Locker Room\p100 plumbing.dwg

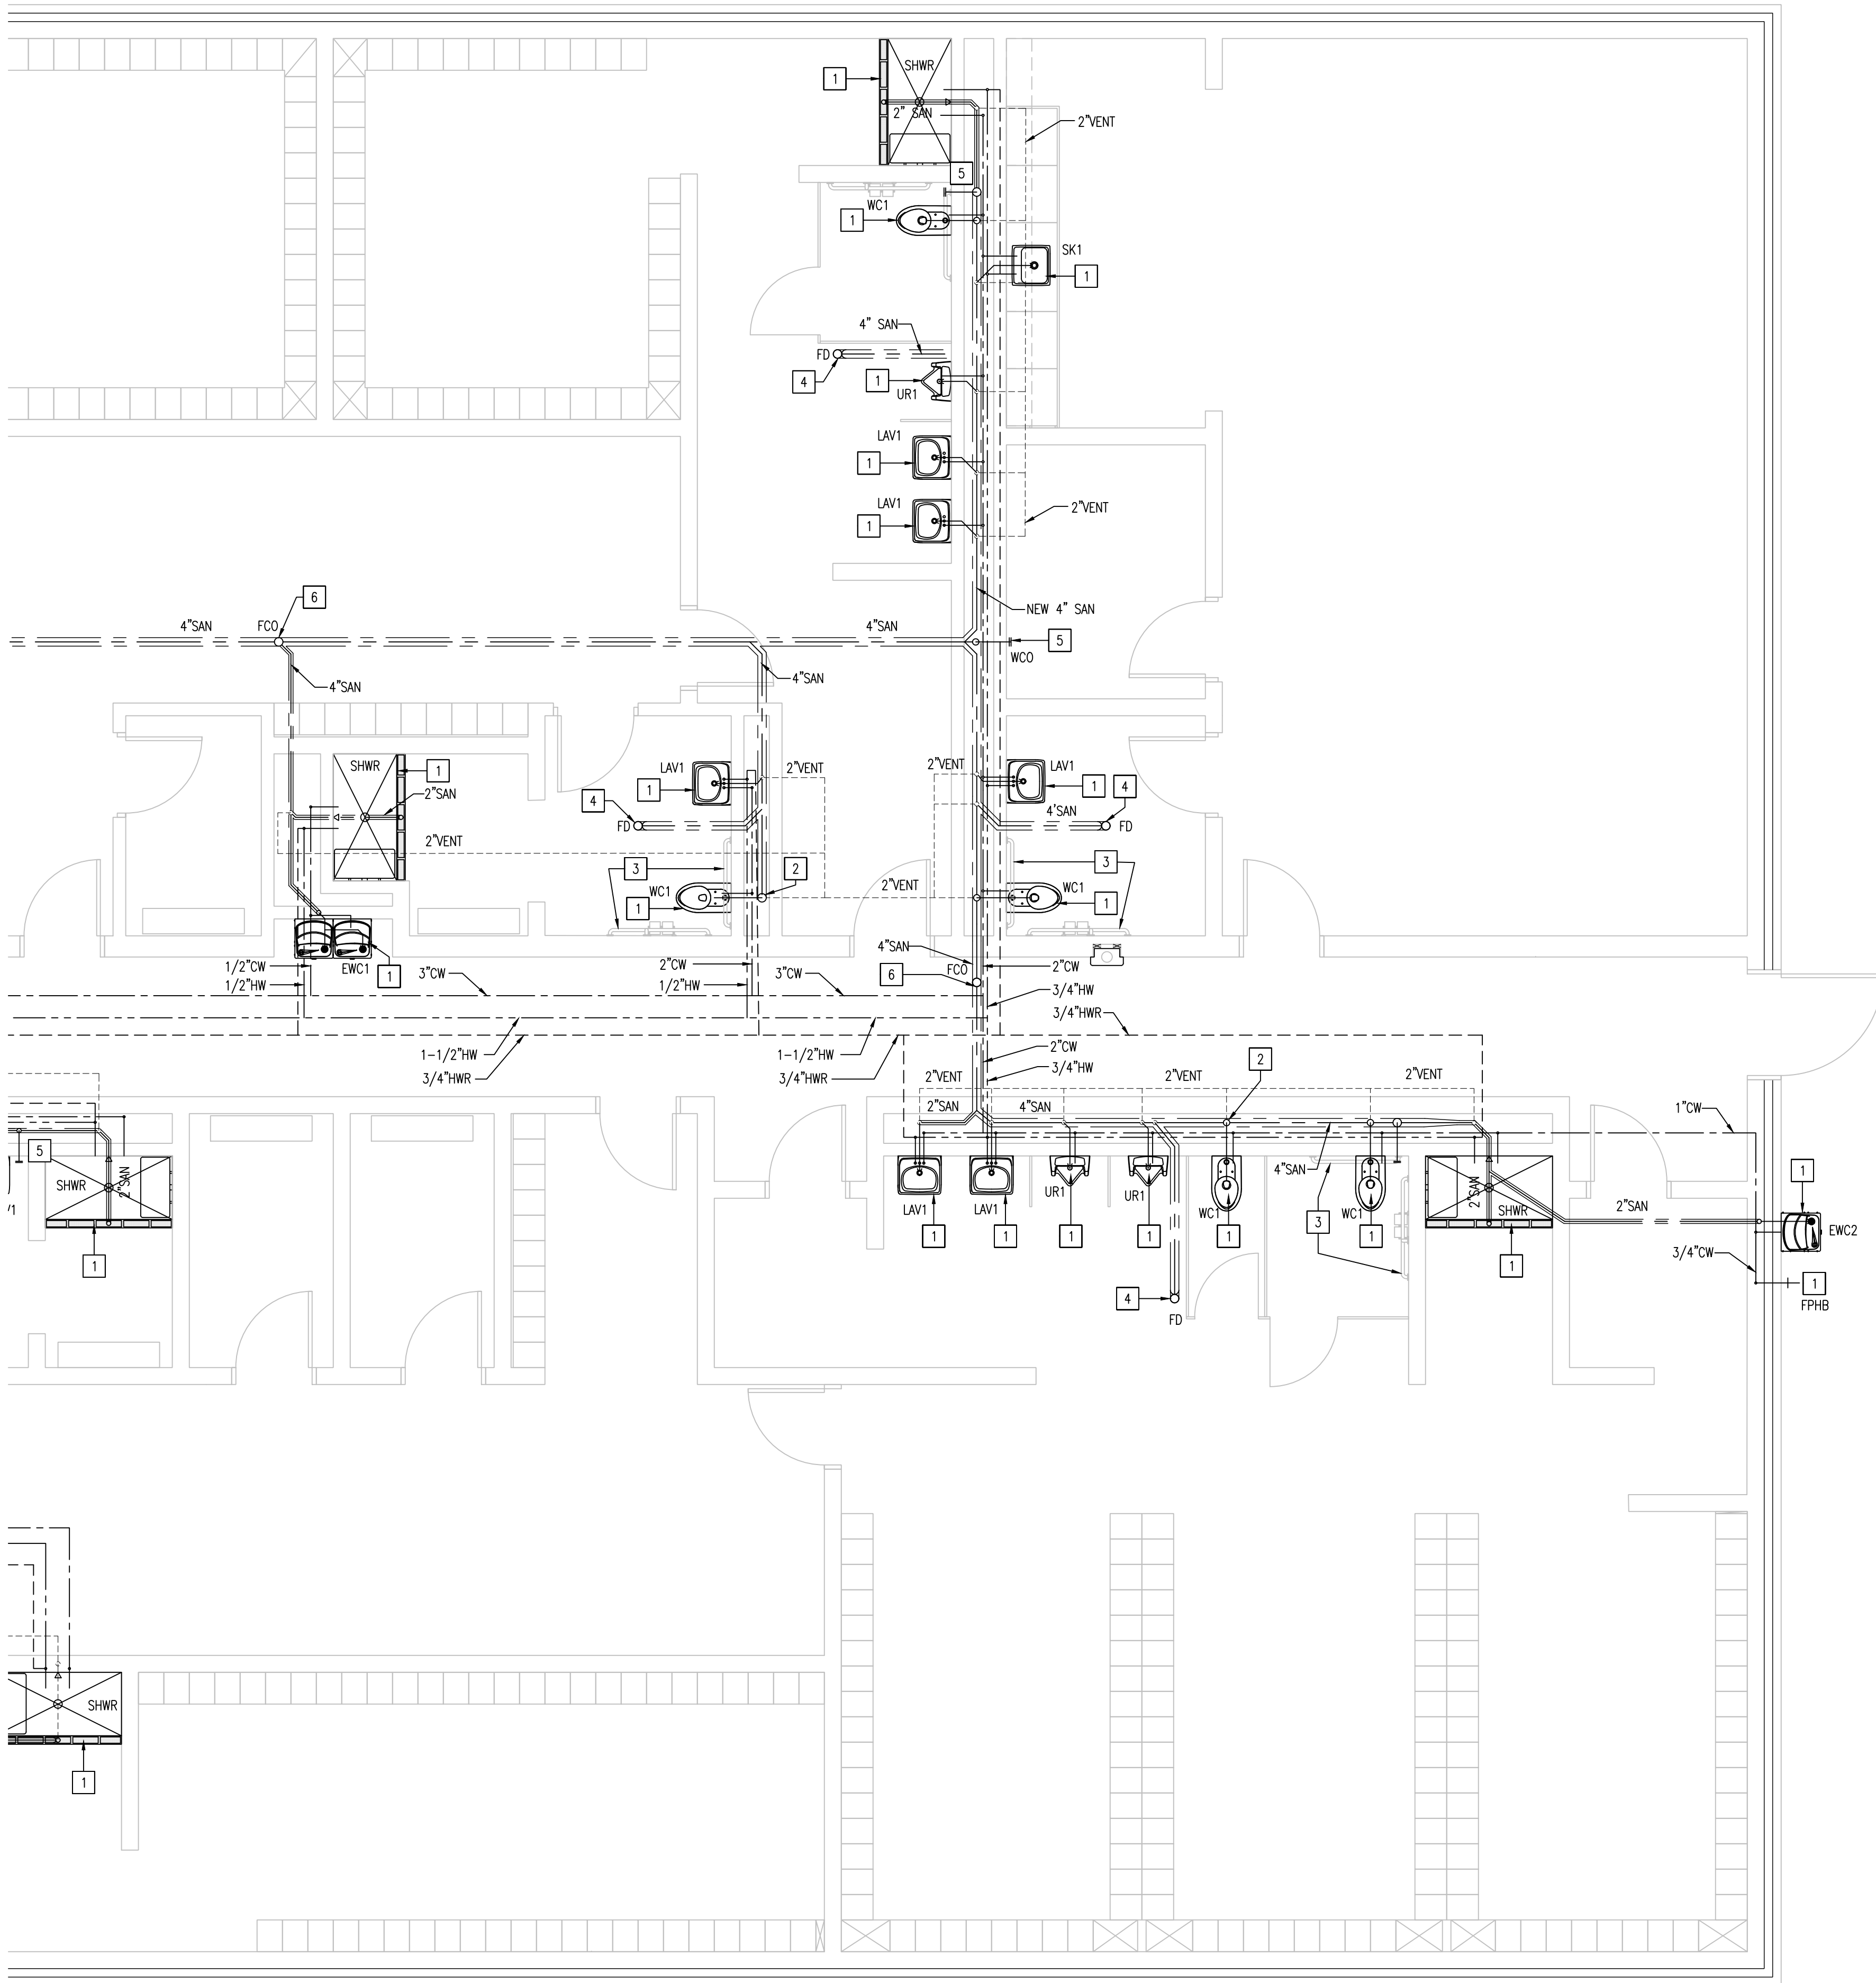

PLUMBING PLAN GENERAL NOTES:

1. FIELD VERIFY ALL DIMENSIONS & CONDITIONS PRIOR TO CONSTRUCTION.
2. ALL WORK, NEW PIPING SIZE AND MATERIAL SHALL BE IN FULL ACCORDANCE WITH THE PLUMBING CODE.
3. ALL PLUMBING FIXTURE VENTS TO TERMINATE A MINIMUM OF 12 INCHES FROM ANY VERTICAL SURFACE AND 10'-00" FROM OR 3'-00" ABOVE ANY MECHANICAL EQUIPMENT OUTSIDE AIR INTAKE.
4. EXTEND AND FLASH ALL PLUMBING VENTS AS REQUIRED.
5. FIRE CAULK AT ALL PIPE OPENINGS THRU FLOORS, WALLS AND ROOFS.
6. INSULATE COLD WATER LINES AT UNCONDITIONED SPACE.
7. PROVIDE PVC P-TRAPS FOR DRAIN LINES OF ALL NEW SINKS.
8. PIPING LAYOUT IS SCHEMATIC ONLY, EXACT ROUTING AND INSTALLATION OF PIPES TO BE COORDINATED WITH THE BUILDING STRUCTURE AND THE WORK OF OTHER CONTRACTORS. NO WATER OR DRAIN LINES ARE PERMITTED TO BE INSTALLED OVER OR UNDER ELECTRICAL PANEL.

PLUMBING PLAN KEYNOTES:

1. NEW PLUMBING FIXTURE CONNECT VIA NEW WATER SUPPLY LINES AND AND SANITARY SYSTEM. REFER TO PLUMBING FIXTURE SCHEDULE THIS SHEET.
2. NEW 4" DIA. PVC VENT THRU ROOF (VTR) - PROVIDE ROOF FLASHING AS REQUIRED.
3. NEW ADA GRAB BARS - REFER TO INTERIOR ELEVATIONS
4. NEW FLOOR DRAIN-REFER TO SPECIFICATION.
5. NEW WALL CLEANOUT- REFER TO SPECIFICATION.
6. NEW FLOOR CLEANOUT - REFER TO SPECIFICATION.
7. NEW 3" DOMESTIC WATER METER W/STRAINER, VALVES, BYPASS, AND BACKFLOW PREVENTER PROVIDED AND INSTALLED BY LOCAL WATER COMPANY.

PLUMBING PIPE LEGEND

COLD WATER SUPPLY PIPING	CW
HOT WATER SUPPLY PIPING	HW
HOT WATER RETURN PIPING	HWR
SANITARY SEWER PIPING	SAN
UNDER FLOOR SANITARY SEWER PIPING	SAN
PVC VENT PIPING	VENT
CTC	CONNECT TO EXISTING


PARTIAL PLUMBING PLAN

AREA B

SCALE: 1/4" = 1'-0"



SHEET ISSUED IN ENTIRETY

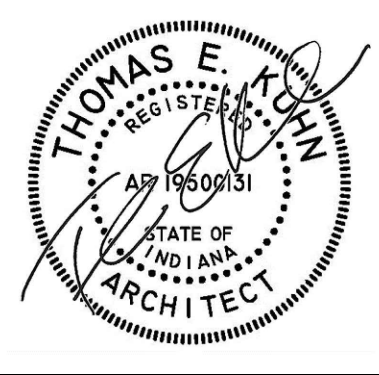

DATE
10-02-2026
10-07-2026
10-20-2026 - ADD#6


NEW LOCKER ROOM FACILITY & RENOVATIONS TO
THE EXISTING CONCESSION & TENNIS FACILITY AT
MERRILLVILLE HIGH SCHOOL
276 E. 68TH PLACE
MERRILLVILLE, IN 46410

CSK ARCHITECTS, P.C.

6919 W. LINCOLN HIGHWAY
219-322-5950
www.cskarchitects.com

26027

SHEET
P
1.1.2-A

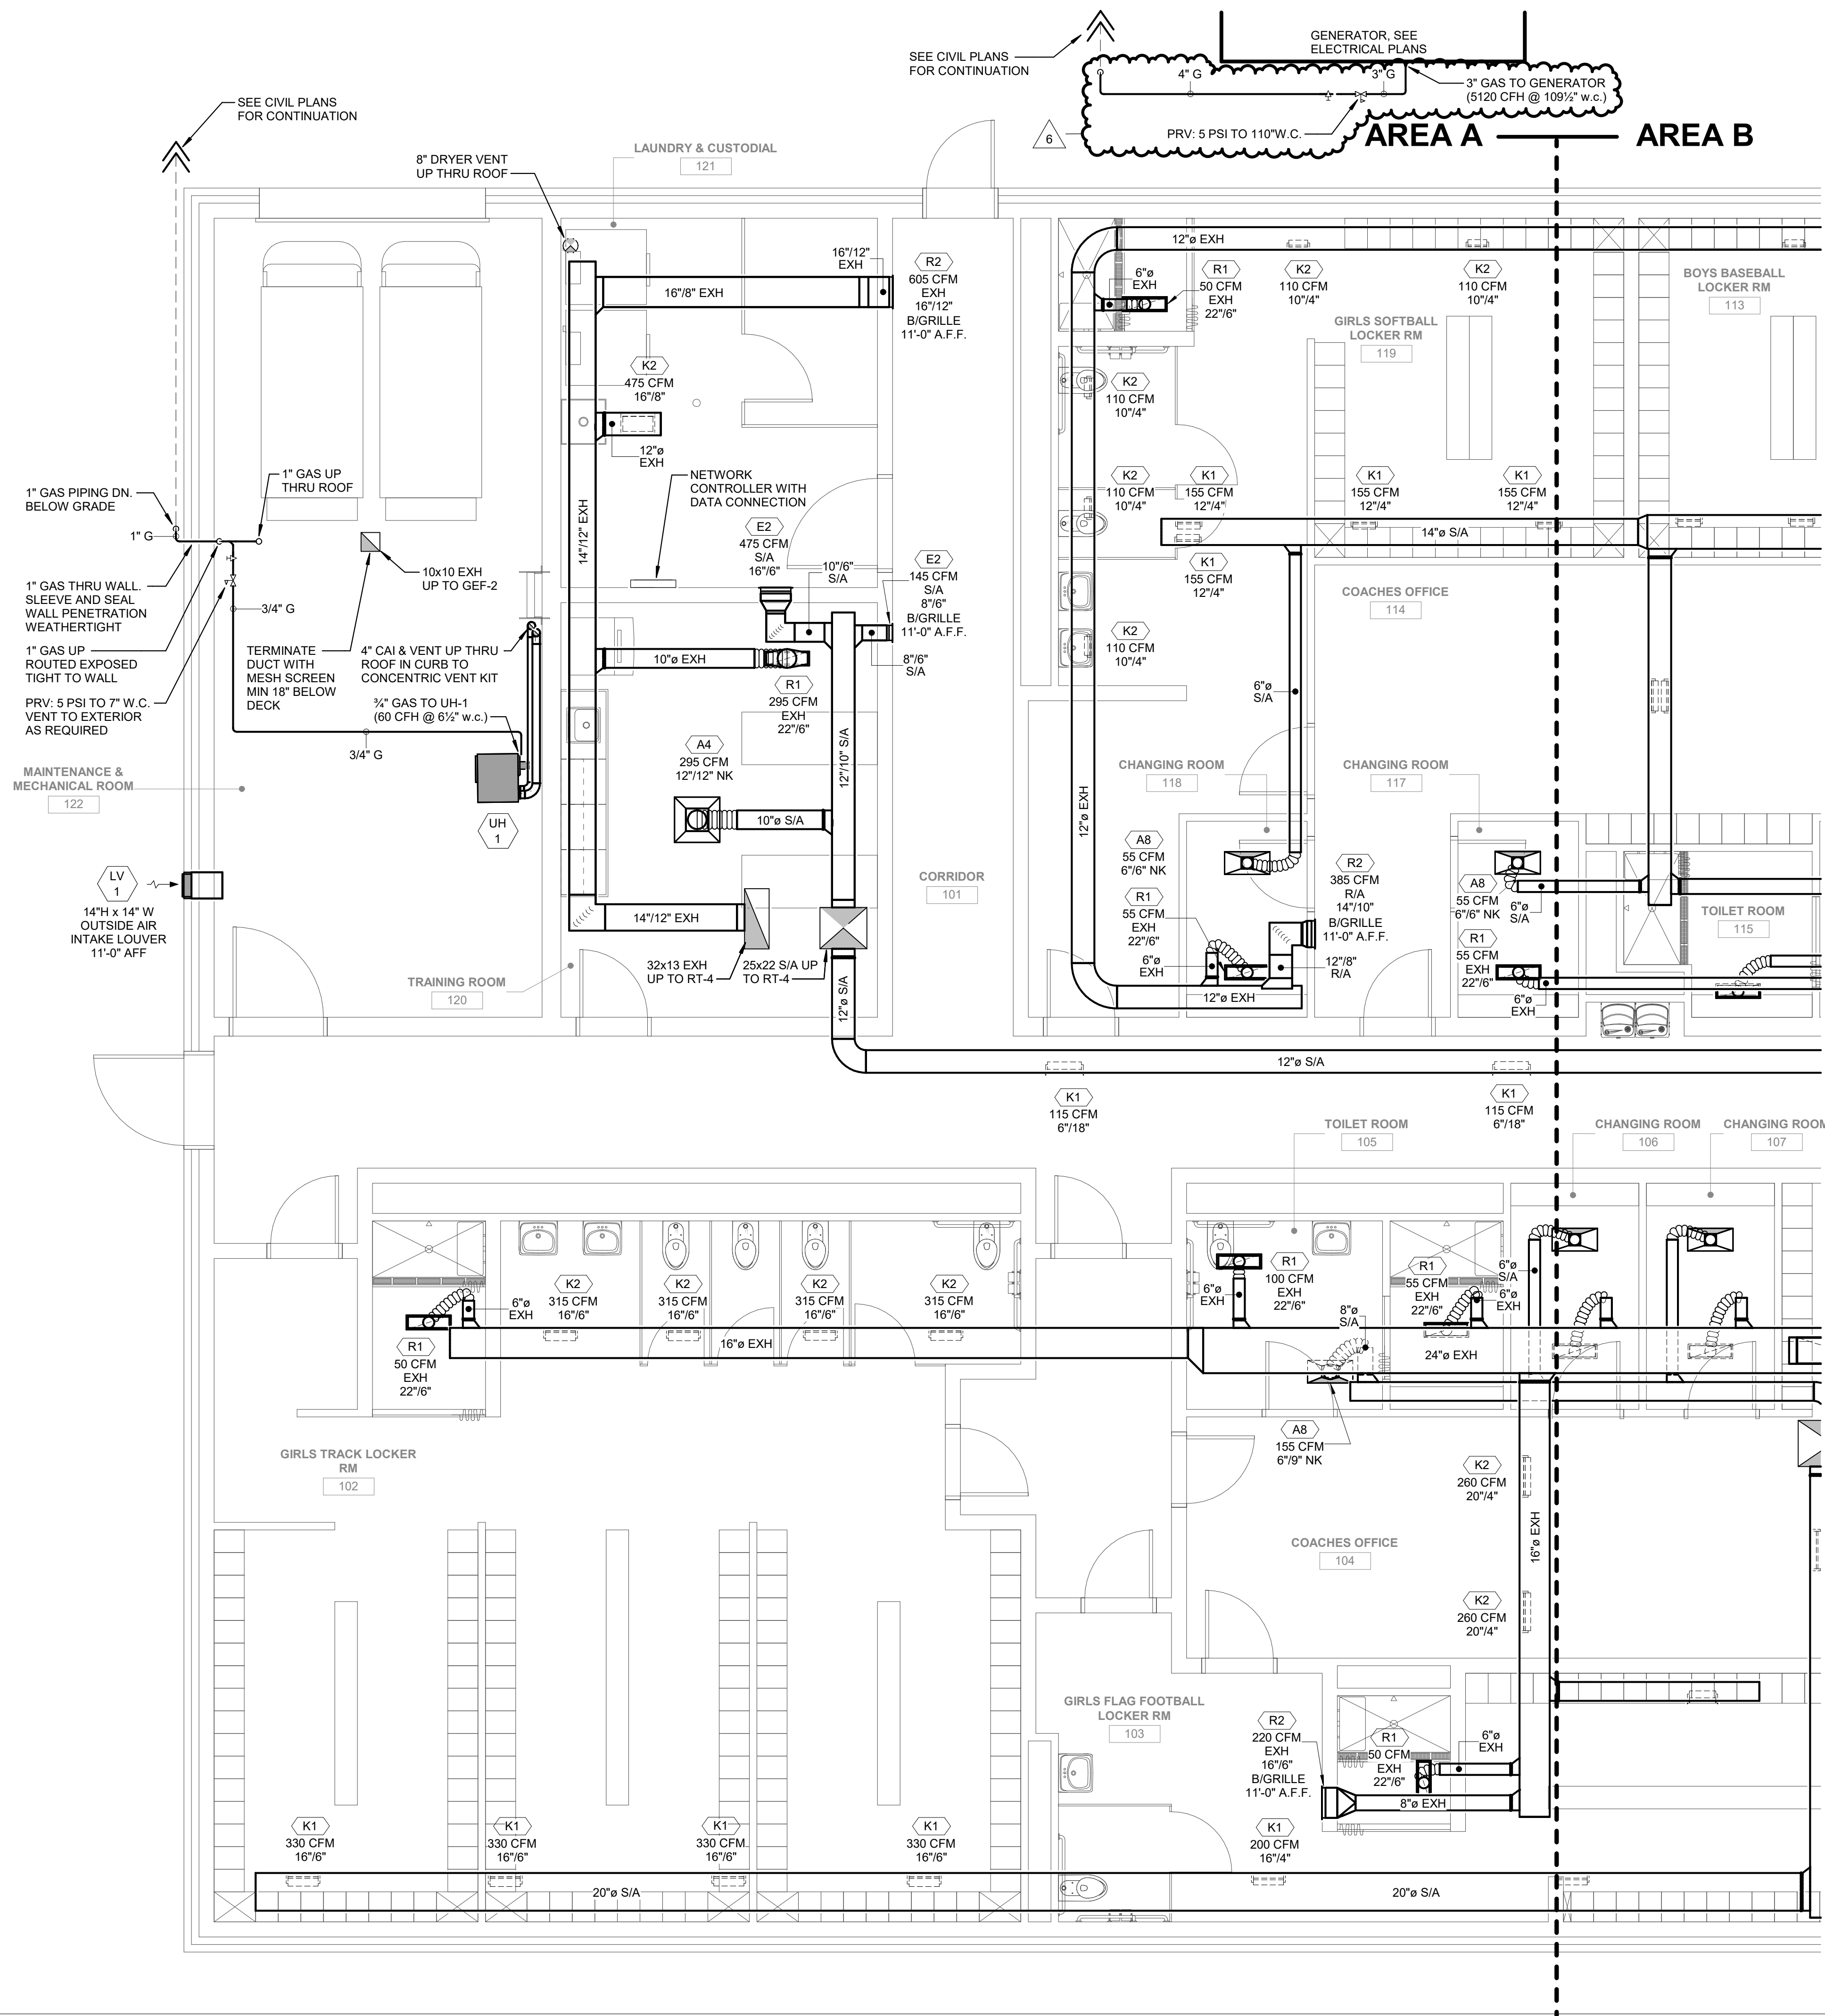

MECHANICAL HVAC FLOOR PLAN
LOCKER ROOM FACILITY

SCALE: 1/4" = 1'-0"



DATE
10/02/2026
10/12/2026
10/20/2026


NEW LOCKER ROOM FACILITY & RENOVATION TO
THE EXISTING RESTROOM FACILITY AT
MERRILLVILLE HIGH SCHOOL
276 E. 68TH PLACE
MERRILLVILLE, IN 46410



26027

SHEET
M
1.1.0-A

X:\Merrillville Schools\26027 New Locker Facility & Renovation to Tennis Bldg\Drawings\Z_Blg B_Tennis\1a700 Interior Elevations.dwg

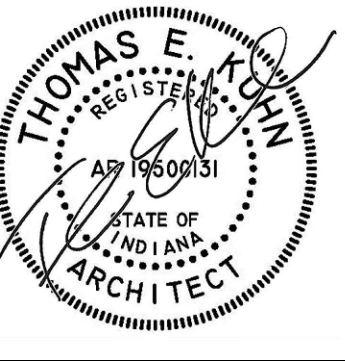

DATE
10-02-2026
10-09-2026 - ADD#2
10-20-2026 - ADD#6


NEW LOCKER ROOM FACILITY & RENOVATIONS TO
THE EXISTING CONCESSION & TENNIS FACILITY AT
MERRILLVILLE HIGH SCHOOL
276 E. 68TH PLACE
MERRILLVILLE, IN 46410

CSK ARCHITECTS, P.C.

6919 W. LINCOLN HIGHWAY
219-322-5950
CROWN POINT, IN 46307
www.cskarchitects.com

26027

SHEET
A
7.1.0-B

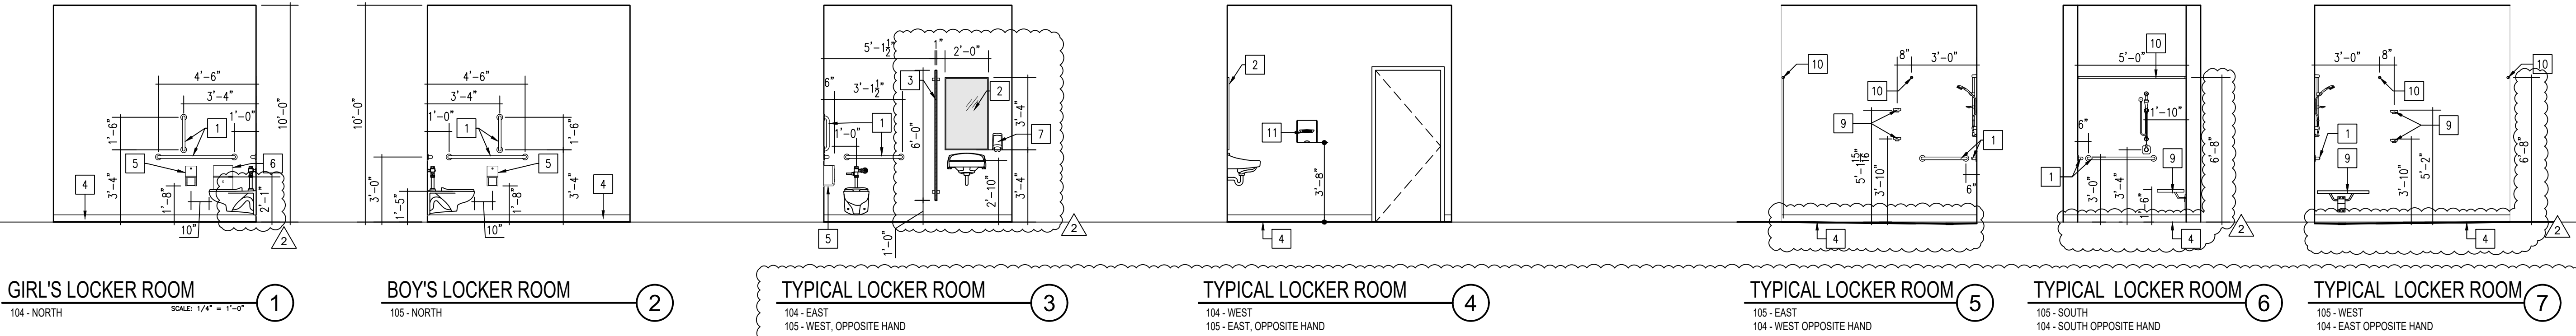


INTERIOR ELEVATIONS

SCALE: NOTED

INTERIOR ELEVATIONS KEY NOTES


1. ADA GRAB BARS - BOBRICK MODEL B5806
2. MIRROR - BOBRICK MODEL B-165 MIRROR - 24"x40"
3. PLASTIC TOILET PARTITIONS
4. BASE - REFER TO ROOM FINISH SCHEDULED (TYP)
5. TOILET TISSUE DISPENSER - BOBRICK MODEL B-2888, MOUNT AT 1'-8"
6. SURFACE-MOUNTED SANITARY NAPKIN DISPOSAL - BOBRICK MODEL: B-254, MOUNT 25" FROM BOTTOM OF OPENING.
7. SOAP DISPENSER -BOBRICK MODEL B-4112, MOUNT 3'-4" FROM BOTTOM
8. ROBE HOOK - BOBRICK B-76727, MOUNT AT 3'-10" AND 5'-2"
9. WALL MOUNTED ADA FOLDING BENCH
10. SHOWER ROD & CURTAIN
11. ELECTRIC HAND DRYER - MODEL: XL-W-ECO--8N-110/120V.

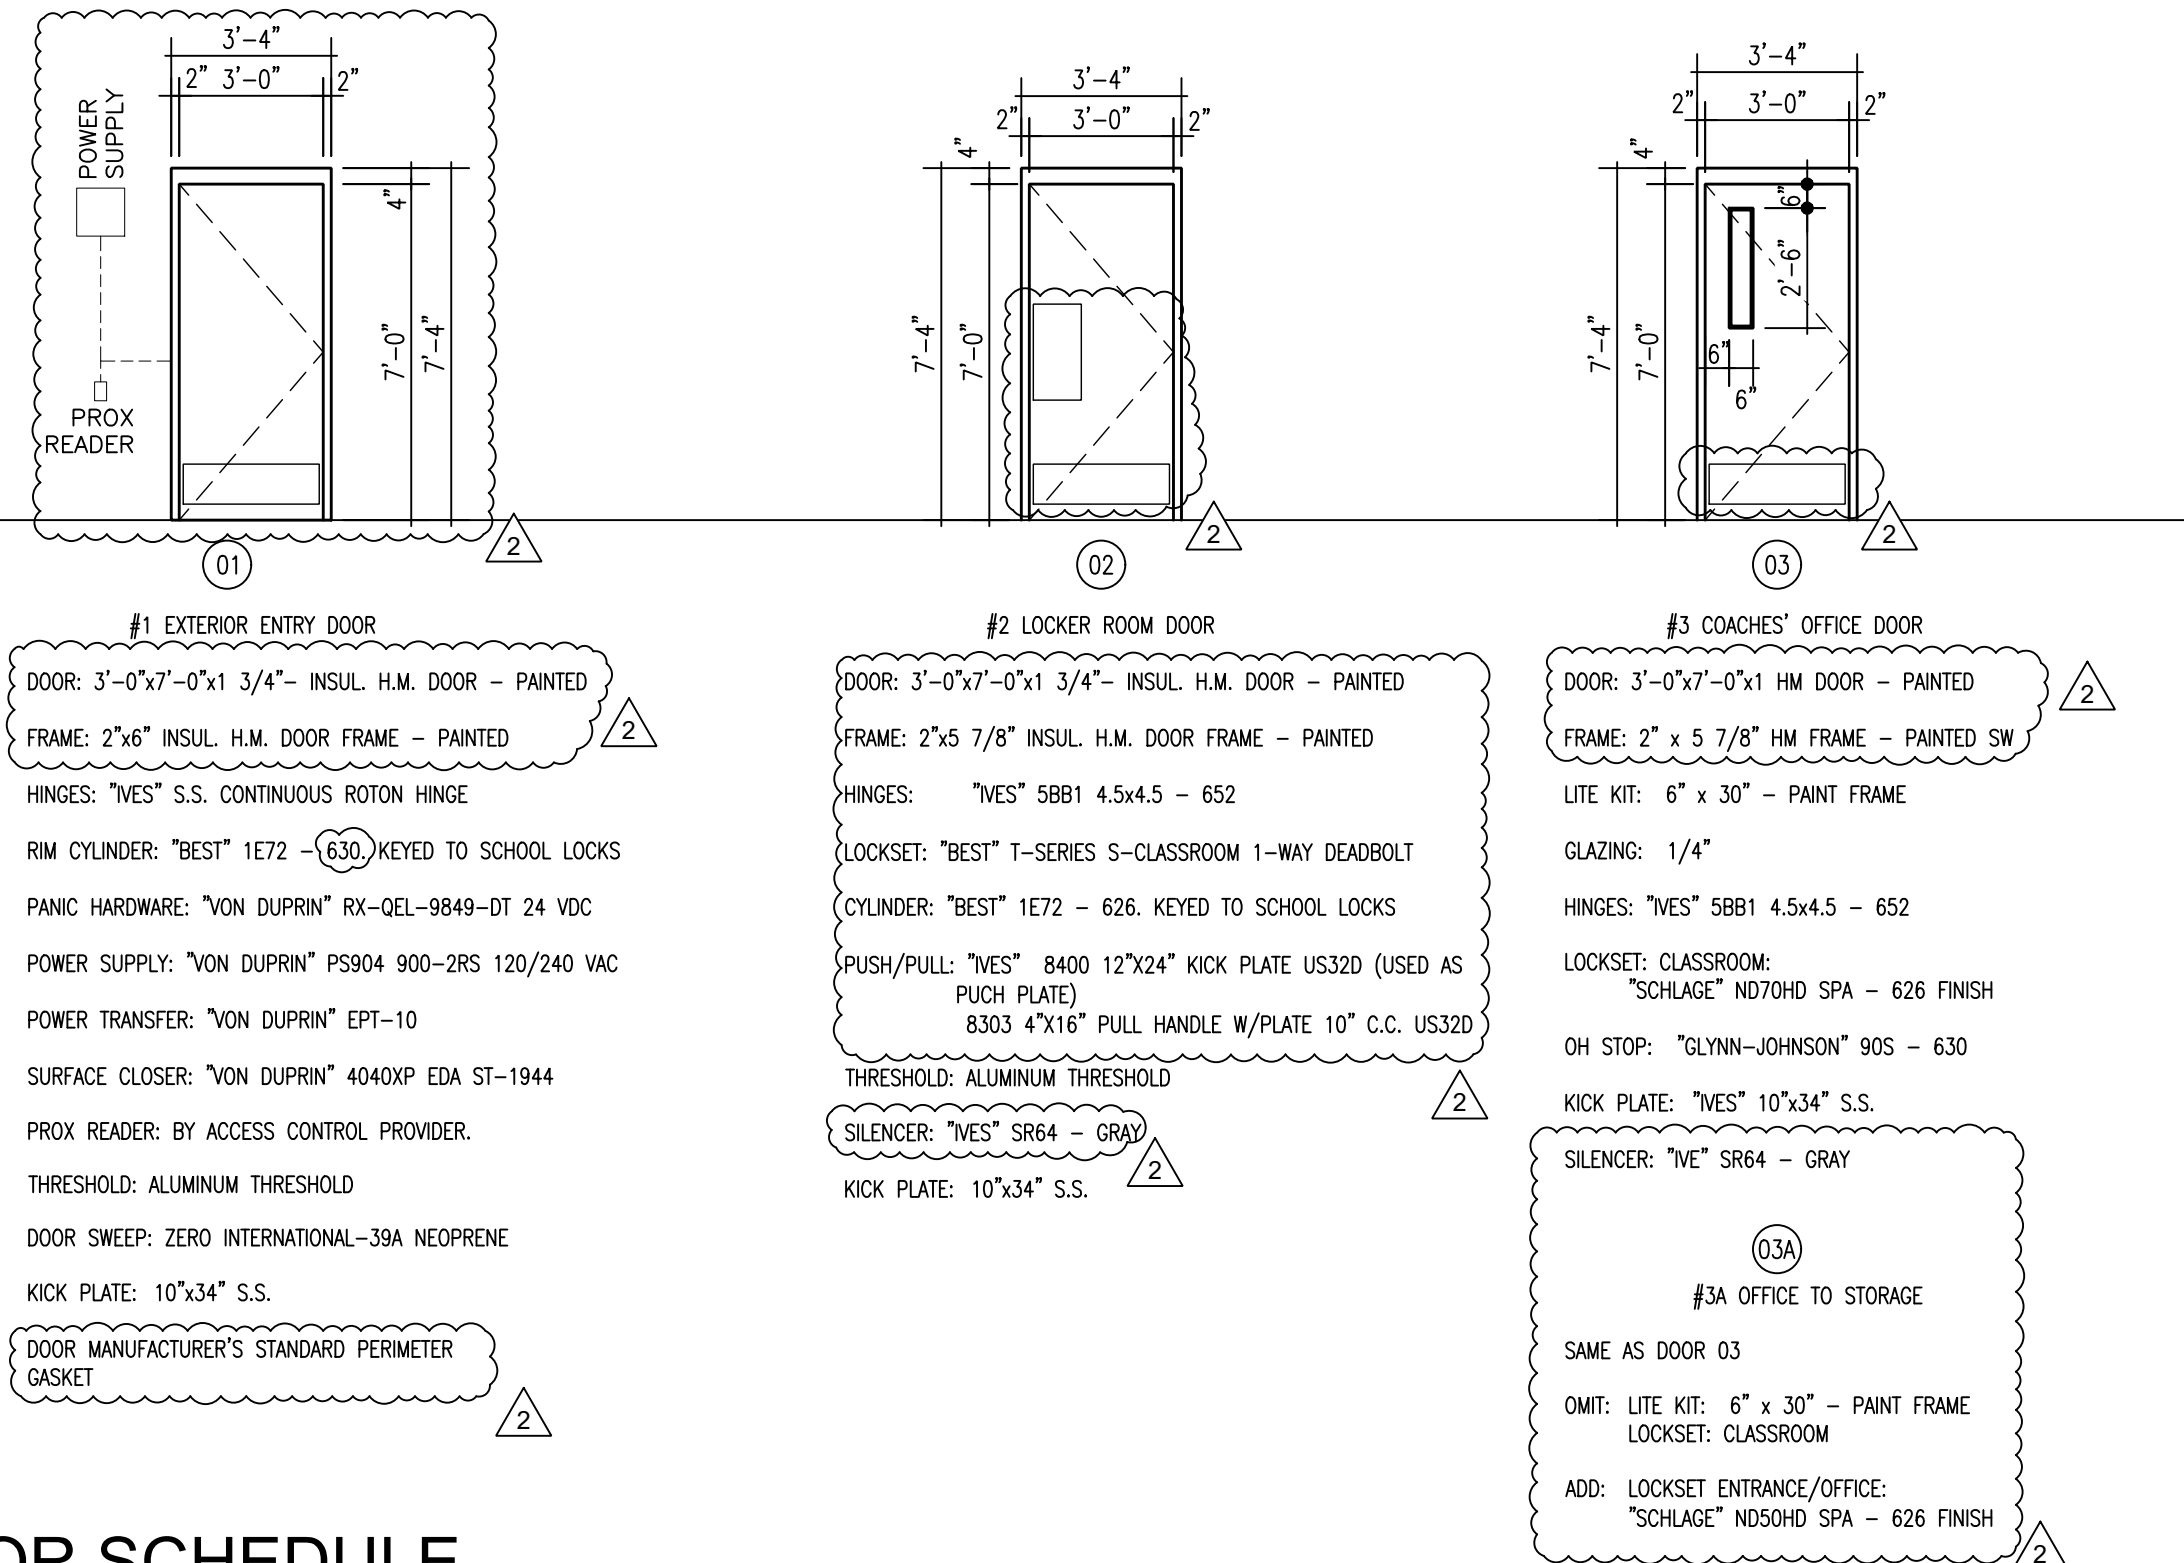

DOOR SCHEDULE

SCALE: NOTED

WALL PAINT DETAIL

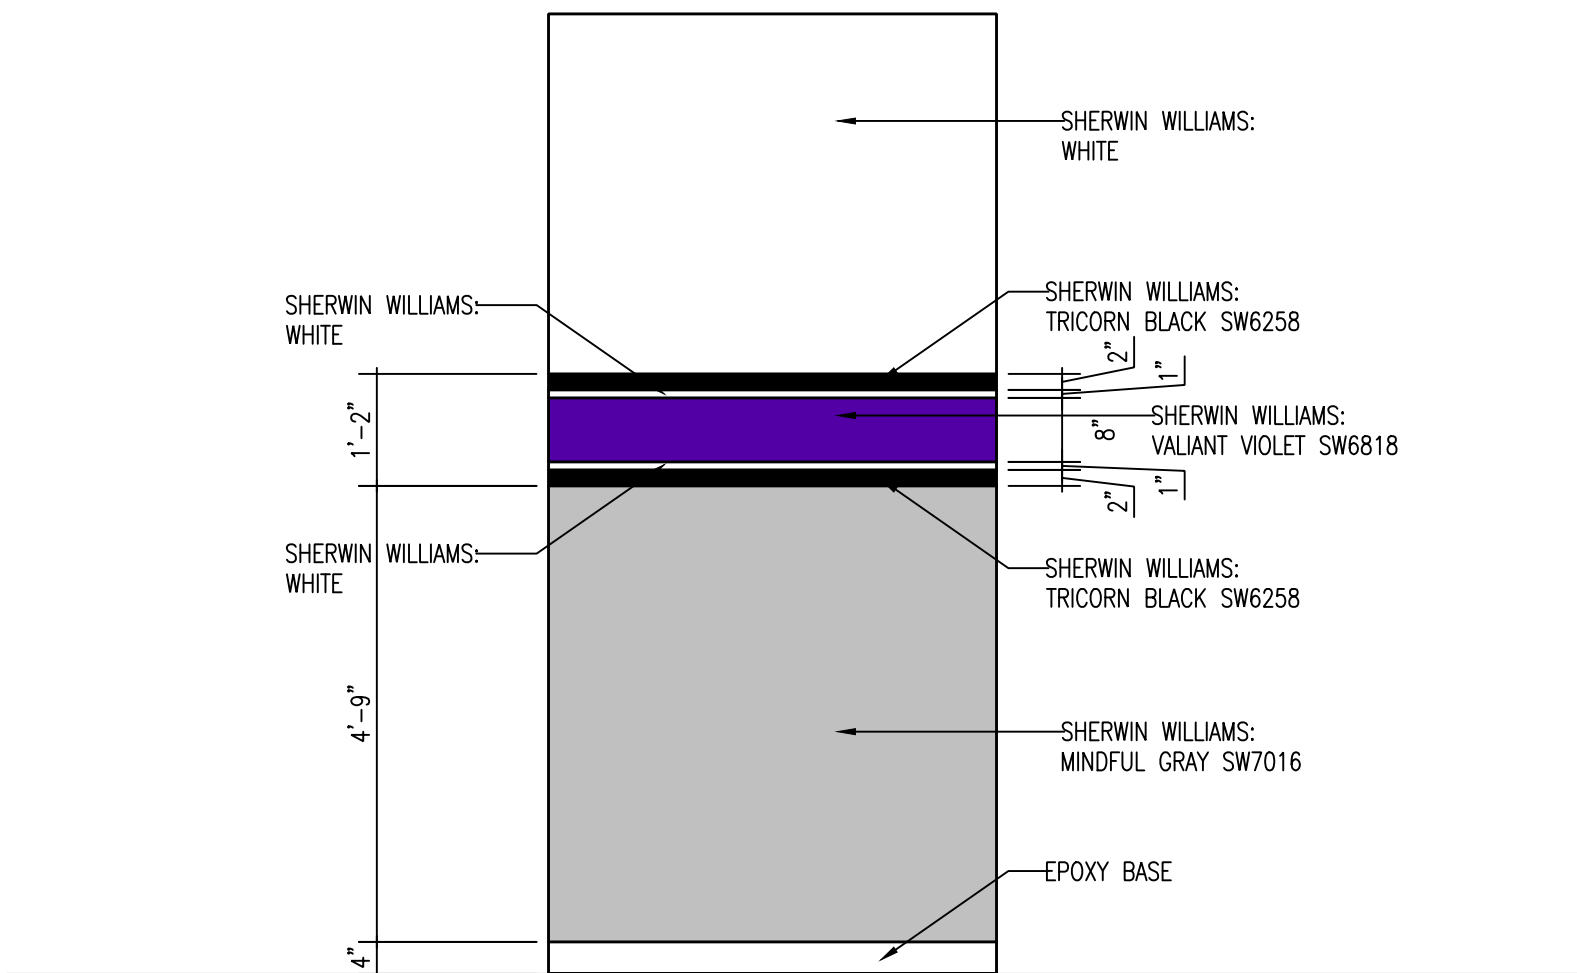

FINISH MATERIAL LEGEND

	DESCRIPTION
CMU	CONCRETE MASONRY UNIT
CONC	SEALED COLORED CONCRETE FLOORS
EB	4" PAINTED EPOXY WALL BASE
RF	RESINOUS FLOOR
RFEF	RESINOUS FLOOR EPOXY BASE
PNT1	WALL PAINT: EPOXY PAINT - SEE NOTE #1 BELOW
PNT2	CEILING PAINT:
SAT	WASHABLE SUSPENDED ACOUSTICAL TILE CEILING

ROOM FINISH SCHEDULE NOTES

- #1: REFER TO PAINT DETAIL PLAN ON SHEET A7.1.1
#2: REFER TO SHEET A2.1.0 REFLECTED CEILING PLAN FOR MORE INFORMATION FOR CEILING HEIGHTS.


ROOM FINISH SCHEDULE

ROOM NO	ROOM NAME	FLOOR	BASE	WALLS								CEILING			NOTES	ROOM NO
				NORTH		SOUTH		WEST		EAST		MTL	FIN	HGT		
				MTL	FIN	MTL	FIN	MTL	FIN	MTL	FIN					
100	EXISTING TOILET	CONC	EB	CMU	PNT1	CMU	PNT1	CMU	PNT1	CMU	PNT1	GYP	PNT2	10'-0"	#1, #2	100
101	EXISTING TOILET	CONC	EB	CMU	PNT1	CMU	PNT1	CMU	PNT1	CMU	PNT1	GYP	PNT2	10'-0"	#1, #2	101
102	EXISTING STORAGE	CONC	EB	CMU	PNT1	CMU	PNT1	CMU	PNT1	CMU	PNT1	EX	---	EX	#1, #2	102
103	COACHES OFFICE	CONC	EB	CMU	PNT1	CMU	PNT1	CMU	PNT1	CMU	PNT1	GYP	PNT2	10'-0"	#1, #2	103
104	GIRL'S LOCKER ROOM	RF	RFEB	CMU	PNT1	CMU	PNT1	CMU	PNT1	CMU	PNT1	GYP	PNT2	10'-0"	#1, #2	104
105	BOY'S LOCKER ROOM	RF	RFEB	CMU	PNT1	CMU	PNT1	CMU	PNT1	CMU	PNT1	GYP	PNT2	10'-0"	#1, #2	105
106	STORAGE ROOM	CONC	EB	CMU	PNT1	CMU	PNT1	CMU	PNT1	CMU	PNT1	EX	---	10'-0"	#1, #2	106
107	HALLWAY	CONC	EB	CMU	PNT1	CMU	PNT1	CMU	PNT1	CMU	PNT1	GYP	PNT2	10'-0"	#1, #2	107

ROOM FINISH SCHEDULE


SCALE: NOTED

SHEET ISSUED IN ENTIRETY

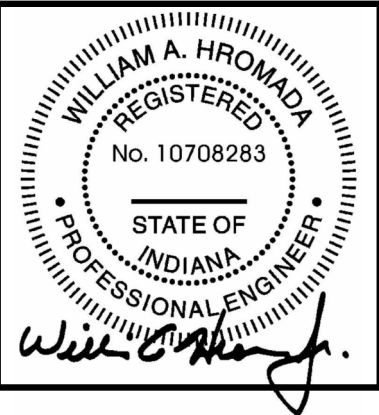

DATE
10/02/2026
10/12/2026
10/20/2026

NEW LOCKER ROOM FACILITY & RENOVATION TO
THE EXISTING RESTROOM FACILITY AT
MERRILLVILLE HIGH SCHOOL
276 E. 68TH PLACE
MERRILLVILLE, IN 46410

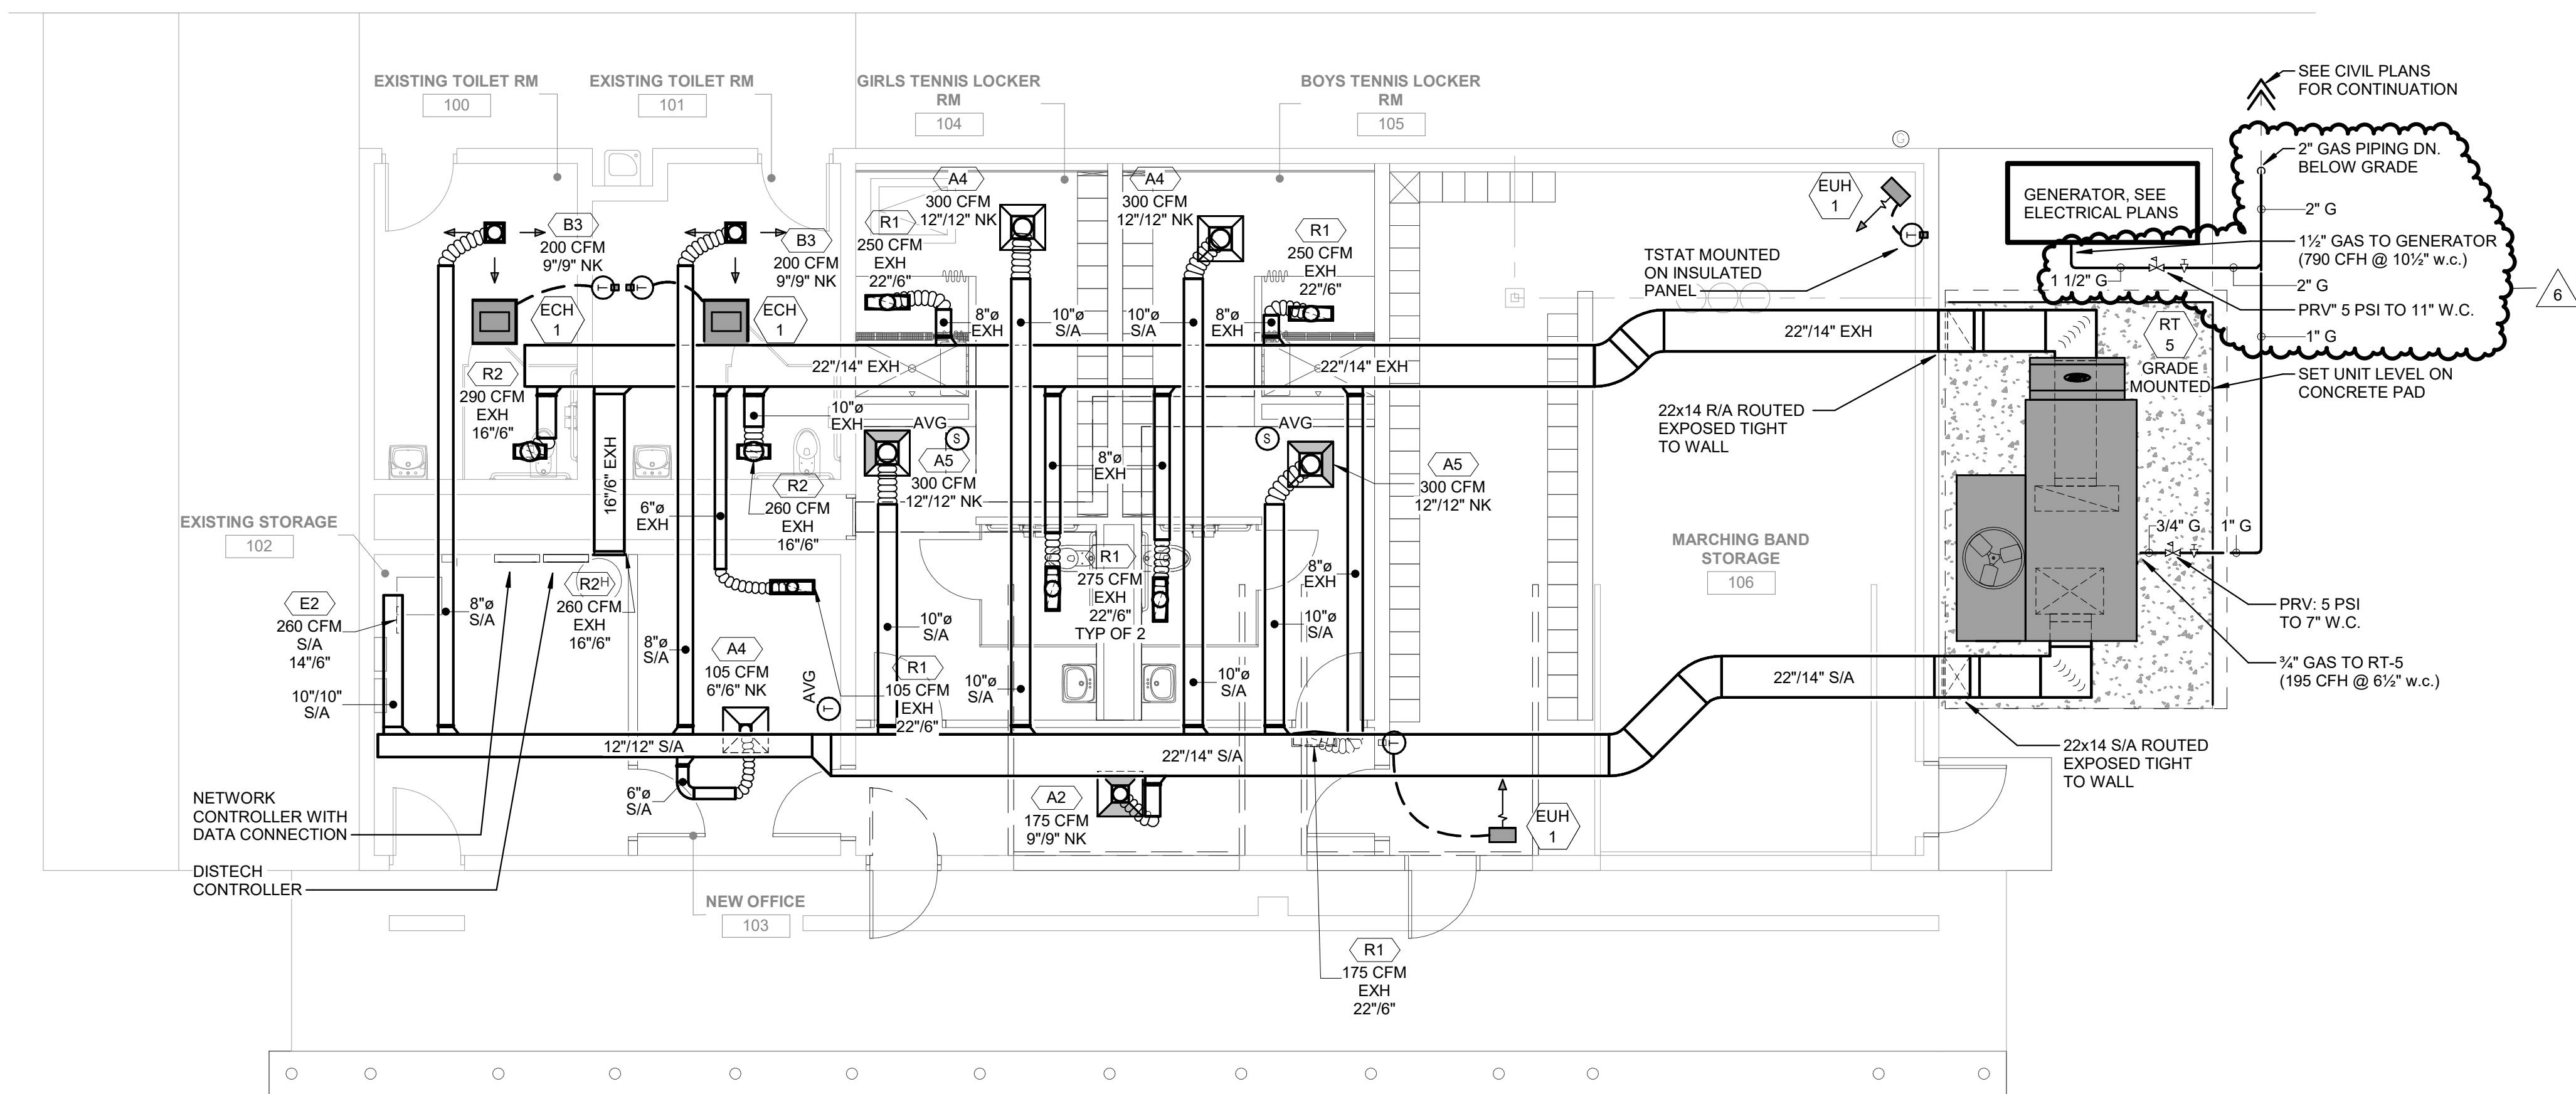

MECHANICAL HVAC FLOOR PLAN
TENNIS & MARCHING FACILITY SCALE: 3/16" = 1'-0"



9711 Valparaiso Drive
221 N. LaSalle Street
8200 Monroe Ave NW
Munster, IN 46321
Chicago, IL 60601
Grand Rapids, MI 49503
(219) 924-8400
www.milliesengineeringgroup.com
Copyright © 2026 Millies Engineering Group

MECHANICAL EQUIPMENT SCHEDULE																																											
TAG	MANUFACTURER	MODEL	DESCRIPTION	EFFICIENCY	FAN MOTOR DATA					EXHAUST FANS					DX COOLING EQUIPMENT/COIL DATA								GAS FIRED HEATING EQUIPMENT DATA					ELECTRICAL DATA										UNITS CONTROLLED BY	EQUIPMENT WEIGHT	REMARKS			
					CFM	MIN. OAI CFM	ESP	BHP	HP	RPM	CFM	ESP	BHP	HP	RPM	MBH	SHC	EDB	EWB	LDB	LWB	CAT	STAGES	MBH (IN)	MBH (OUT)	EAT	LAT	STAGES	LOAD				VOLT	PHASE	HZ	DISCONNECT SWITCH:					STARTER:		
																													PROV. BY:	M.C.	E.C.	M.C.				E.C.							
RT-1	AAON	RNA-009-B	ROOF MOUNTED DX COOLING/GAS FIRED ROOFTOP UNIT (DOAS w/ ERV)	16.56 IEER	2140	2140	1	1.56	2	2098	2140	0.5	0.88	2	1306	162.3	94.8	79.7	65.7	54.2	51.8	95	MOD	195	158	49.8	119.4	MOD	HP	MCA	FLA	MOCp	480	3	60	X		X			FMS	1895	NOTE 1
RT-2	AAON	RNA-007-A	ROOF MOUNTED DX COOLING/GAS FIRED ROOFTOP UNIT (DOAS w/ ERV)	14.8 IEER	1630	1630	1	1.23	2	1818	1630	0.5	0.59	1	1449	121.8	70.9	79.9	65.9	55	52.2	95	MOD	90	72.9	48.7	90.9	MOD		21	18	30	480	3	60	X		X			FMS	1125	NOTE 2
RT-3	AAON	RQA-005-A	ROOF MOUNTED DX COOLING/GAS FIRED ROOFTOP UNIT (SZVAV)	13.4 SEER2	1300	325	1	1.12	2	1620	1300	0.5				56.4	38.7	79	65.6	52.9	51.2	95	MOD	60	48.6	52.5	87.8	MOD		15	13	20	480	3	60	X		X			FMS	1880	NOTE 1
RT-4	AAON	RNA-006-A	ROOF MOUNTED DX COOLING/GAS FIRED ROOFTOP UNIT (DOAS w/ ERV)	14.8 IEER	1370	1370	1	1.07	2	1759	1370	0.5	0.41	1	1296	106	61.5	79.3	65.4	53.6	51.1	95	MOD	90	72.9	51.2	101.4	MOD		19	17	25	480	3	60	X		X			FMS	3010	NOTE 1
RT-5	AAON	RNA-011-B	GRADE MOUNTED DX COOLING/GAS FIRED ROOFTOP UNIT (DOAS w/ ERV)	18.33 IEER	2920	2920	1	2.28	3	1812	2920	0.25	0.93	2	1174	204	123.9	81.8	67.1	55.9	54	95	MOD	195	158	40.5	91.6	MOD		91	85	110	240	1	60	X		X			FMS	65	NOTE 3
UH-1	REZNOR	UDXC-45	SUSPENDED GAS FIRED UNIT HEATER		630		0.1																	45	26.1	40	95	1			2.4	120	1	60	X		X			WALL MTD TSTAT	36	NOTE 4	
GEF-1	GREENHECK	G-070-E	ROOF MOUNTED GENERAL EXHAUST FAN - 112 KITCHENETTE								135	0.35	0.02	1/15	1451															1.6	1.3	15	120	1	60		X	X			WALL SWITCH	40	NOTE 4
GEF-2	GREENHECK	G-080-E	ROOF MOUNTED GENERAL EXHAUST FAN - 122 MAINTENANCE & MECHANICAL ROOM								300	0.3	0.04	1/10	1437															1.6	1.3	15	120	1	60		X	X			CO SENSOR	36	NOTE 4
TEF-1	GREENHECK	G-070-E	ROOF MOUNTED TOILET EXHAUST FAN								140	0.35	0.02	1/15	1457															1.6	1.3	15	120	1	60		X	X			WALL SWITCH	40	NOTE 4

PROVIDE WITH:

- DISCONNECT SWITCH
- ECM MOTOR WITH POTENTIOMETER
- SPEED CONTROLLER
- MOTORIZED DAMPER
- BIRD SCREEN
- ROOF CURB

SEE SPECIFICATIONS FOR ADDITIONAL REQUIREMENTS.

HEAT RECOVERY SCHEDULE																													
UNIT TAG	ERV		MIXED SUPPLY AIR						RETURN AIR					EXHAUST AIR				OUTSIDE AIR				HEAT RECOVERY DISCHARGE					REMARKS		
	COOLING MBH	HEATING MBH	SUMMER			WINTER			CFM	SUMMER			WINTER		SUMMER		WINTER		CFM	SUMMER		WINTER		SUMMER				WINTER	
			CFM	DB	WB	DB	WB	CFM		DB	WB	DB	WB	CFM	DB	WB	DB	WB		CFM	DB	WB	DB	WB	CFM	DB		WB	DB
RT-1	73.3	169.2	2140	79.7	65.7	49.8	40.9	0	75	62	70	53	2210	90.2	71.9	9.3	9.3	2210	95	75	-10	-11	2140	79.7	65.7	49.8	40.9		
RT-2	54.5	126.2	1630	79.9	65.9	48.7	40.1	0	75	62	70	53	1665	89.9	71.7	10.5	10.4	1665	95	75	-10	-11	1630	79.9	65.9	48.7	40.1		
RT-4	47.7	109.6	1370	79.3	65.4	51.2	41.9	0	75	62	70	53	1400	90.5	72.1	8.1	8	1400	95	75	-10	-11	1370	79.3	65.4	51.2	41.9		
RT-5	85.3	197.6	2920	81.8	67.1	40.5	34.7	0	75	62	70	53	2915	88	70.6	17.5	17.5	2915	95	75	-10	-11	2920	81.8	67.1	40.5	34.7		

MECHANICAL EQUIPMENT SCHEDULE - ELECTRIC HEAT																													
TAG	MANUFACTURER	MODEL	DESCRIPTION	FAN DATA		ELECTRIC HEATING EQUIP./COIL DATA					ELECTRICAL DATA										UNITS CONTROLLED BY	EQUIPMENT WEIGHT	REMARKS						
				S/A CFM	MBH	KW	EAT	LAT	STEPS	LOAD				VOLT	PHASE	HZ	DISCONNECT SWITCH:		STARTER:										
										HP	MCA	FLA	MOCp				M.C.	E.C.	TYPE	M.C.				E.C.					
ECH-1	QMARK	CDF-542	RECESSED CEILING MOUNTED CABINET HEATER	300	13.7	4				1				16.7		240	1	60	X							WALL MTD TSTAT	30	NOTE 1.	
EUH-1	QMARK	MUH047225	SUSPENDED ELECTRIC UNIT HEATER	350	17	5				2				18		240	1	60	X					X			WALL MTD TSTAT	30	NOTE 2.

PROVIDE WITH:

- WALL MTD TSTAT
- DISCONNECT SWITCH

SEE SPECIFICATIONS FOR ADDITIONAL INFORMATION.

GAS CONNECTION SCHEDULE					
TAG	QUANTITY	DESCRIPTION	LOCATION	CAPACITY PER UNIT	TOTAL CAPACITY
	1	GRADE MOUNTED GENERATOR	GRADE	5120	5120
RT-1	1	ROOF MOUNTED DX COOLING/GAS FIRED ROOFTOP UNIT (DOAS w/ ERV)	ROOF	195	195
RT-2	1	ROOF MOUNTED DX COOLING/GAS FIRED ROOFTOP UNIT (DOAS w/ ERV)	ROOF	90	90
RT-3	1	ROOF MOUNTED DX COOLING/GAS FIRED ROOFTOP UNIT (SZVAV)	ROOF	60	60
RT-4	1	ROOF MOUNTED DX COOLING/GAS FIRED ROOFTOP UNIT (DOAS w/ ERV)	ROOF	90	90
UH-1	1	SUSPENDED GAS FIRED UNIT HEATER	122 - MAINTENANCE & MECHANICAL ROOM	45	45
TOTAL @ 5 PSI:				5600	5600

GAS CONNECTION SCHEDULE - EXISTING BUILDING					
TAG	QUANTITY	DESCRIPTION	LOCATION	CAPACITY PER UNIT	TOTAL CAPACITY
	1	GRADE MOUNTED GENERATOR	GRADE	790	790
RT-5	1	GRADE MOUNTED DX COOLING/GAS FIRED ROOFTOP UNIT (DOAS w/ ERV)	GRADE	195	195
TOTAL @ 5 PSI:					985

GRILLE, REGISTER, & DIFFUSER SCHEDULE									
TAG	MANUFACTURER	MODEL	DESCRIPTION	AIR PATTERN	MOUNTING	SIZE	REMARKS		
A2	NAILOR	6500	SUPPLY CEILING DIFFUSER	2-WAY	2' x 2' LAY-IN PANEL	SEE PLANS	-		
A4	NAILOR	6500	SUPPLY CEILING DIFFUSER	4-WAY	2' x 2' LAY-IN PANEL	SEE PLANS	-		
A5	NAILOR	6500	SUPPLY CEILING DIFFUSER	2-WAY CORNER	2' x 2' LAY-IN PANEL	SEE PLANS	-		
A8	NAILOR	6500	SUPPLY CEILING DIFFUSER	3-WAY	2' x 1' LAY-IN PANEL	SEE PLANS	-		
B3	NAILOR	6500	SUPPLY CEILING DIFFUSER	3-WAY	SURFACE-MOUNTED	SEE PLANS	-		
E3	NAILOR	61DH	SUPPLY REGISTER	DOUBLE DEFLECTION	SURFACE-MOUNTED	SEE PLANS	-		HORIZONTAL FRONT BARS, VERTICAL BACK BARS
K1	NAILOR	61DHC	SUPPLY REGISTER	DOUBLE DEFLECTION	DUCT-MOUNTED	SEE PLANS	-		PROVIDE W/ MILL FINISH, ALUMINUM CONSTRUCTION
K2	NAILOR	61DHC	SUPPLY REGISTER	DOUBLE DEFLECTION	DUCT-MOUNTED	SEE PLANS	-		PROVIDE W/ MILL FINISH, ALUMINUM CONSTRUCTION
R1	NAILOR	614SH	RETURN/EXHAUST REGISTER	LOUVERED GRILLE	LAY-IN PANEL	SEE PLANS	-		ALUMINUM CONSTRUCTION
R2	NAILOR	614SH	RETURN/EXHAUST REGISTER	LOUVERED GRILLE	SURFACE-MOUNTED	SEE PLANS	-		ALUMINUM CONSTRUCTION